	INDEX TO DRAWINGS	
SHEET NO.	DESCRIPTION	
1	TITLE SHEET	
2	STANDARD PLAN SUMMARY	
3 – 5	PAVEMENT MARKING & SIGNING	
·	PLANS AND NOTES	
6 – 12	TRAFFIC SIGNAL AND HIGHWAY	
	LIGHTING PLANS, DETAILS AND NOTES	

STATE OF HAWAII

## DEPARTMENT OF TRANSPORTATION

HIGHWAYS DIVISION HONOLULU, HAWAII


"AS-BUILT"

PLANS FOR

## QUEEN KAAHUMANU HIGHWAY

INTERSECTION IMPROVEMENTS AT KEAHOLE AIRPORT ROAD FEDERAL AID PROJECT NO. STP-019-1(21)

DISTRICT OF NORTH KONA
ISLAND OF HAWAII

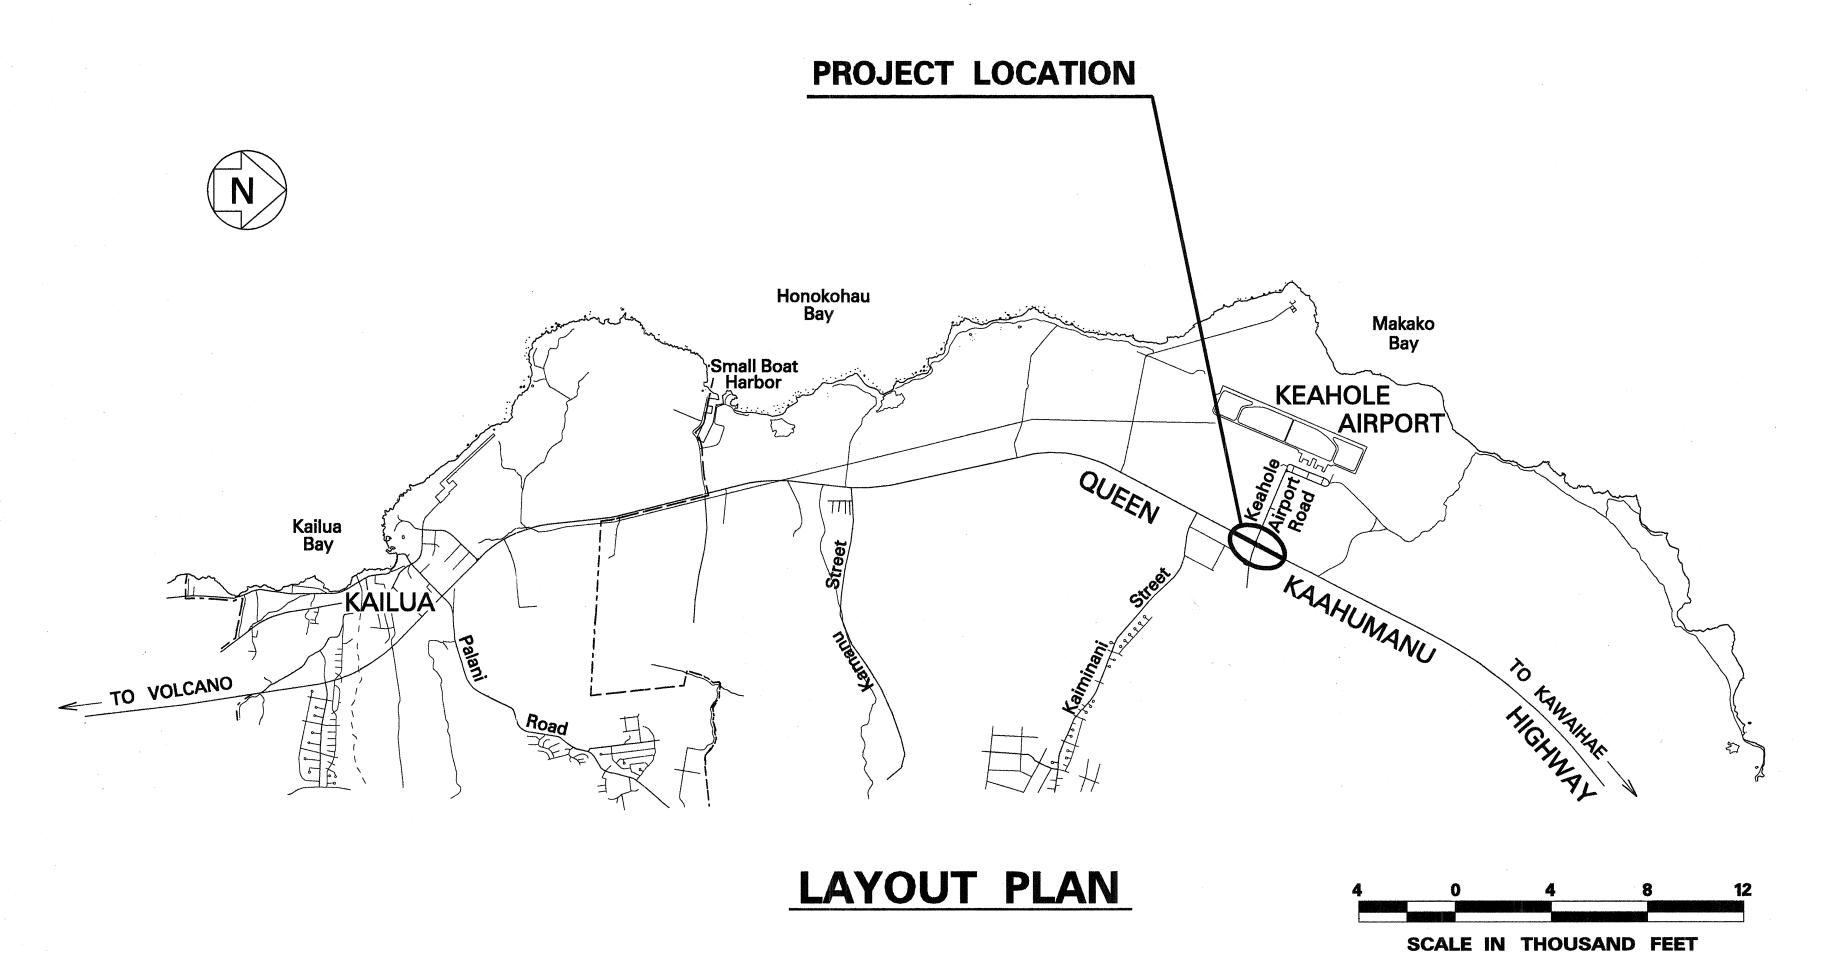

Manuscon North Kohala Wateros South Kohala Wateros South Kohala Wateros South Kohala Kallus Bay Holicia Hondros Kallus Bay Holicia Hondros Kallus Bay Holicia Cook and Kallus Bay Holicia Cook and Kallus Bay Holicia Cook and Kallus Reductor Kallus Bay Holicia Cook and Kallus Reductor Kal

FED. ROAD DIST. NO.

OR UNDER CONSTRUCTION

MILE POST 92.72 TO MILE POST 92.90

---- FEDERAL AID PROJECTS PREVIOUSLY CONSTRUCTED

CHANGES MADE DURING CONSTRUCTION HAVE BEEN INCORPORATED ON THESE PLANS EXCEPT CHANGES IN THE ORIGINAL THEORETICAL QUANTITIES.

RESIDENT ENGINEER DATE

DEPARTMENT OF TRANSPORTATION STATE OF HAWAII			
APPROVE	D:		
Keyn	Bayashide	4/1/96	
DIR. OF	TRANSPORTATION	DATE	

tol.ruby khttsht.dgn