
 


4/25/23-12:11 W:\044\044.097 New\PIERS 1 and 2\044.097 E-2 - E-3.dwg

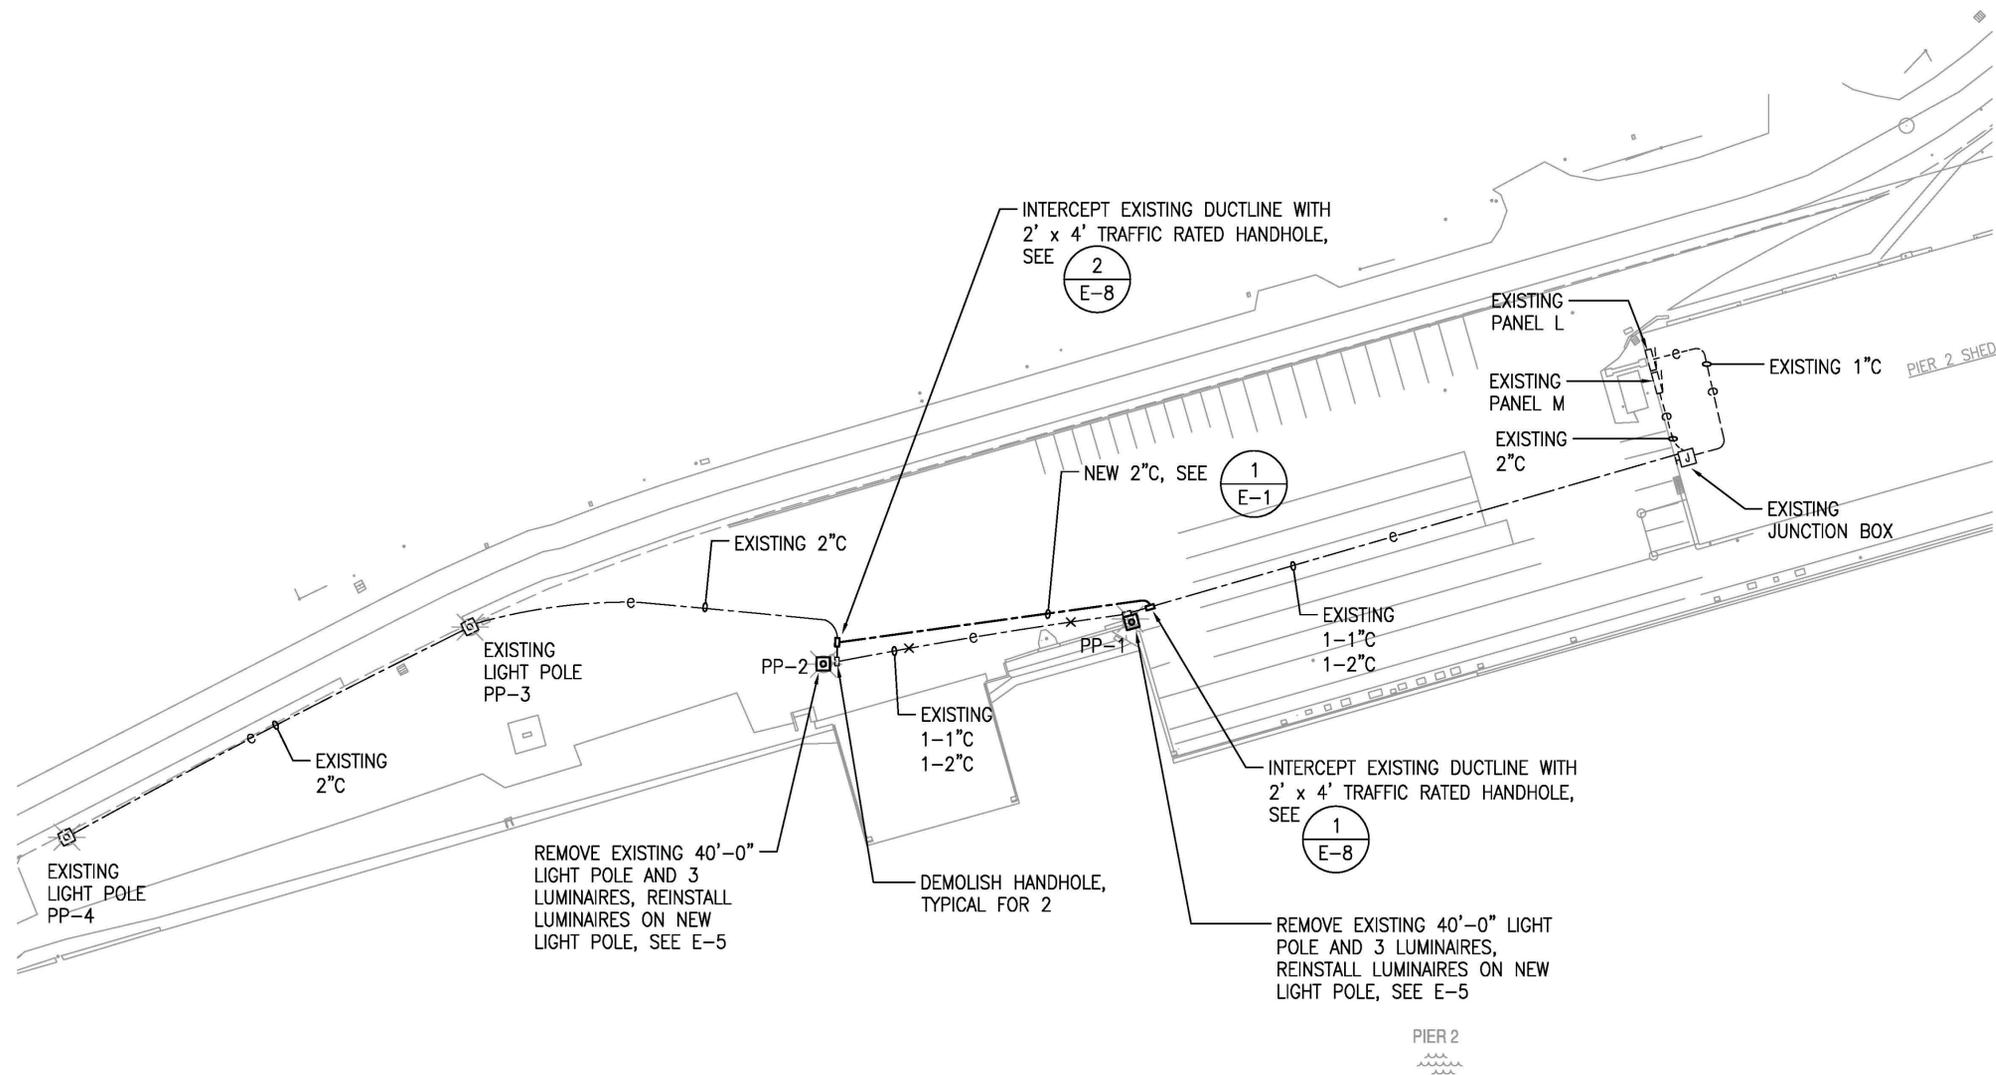

(1) PIER 2 ELECTRICAL SITE PLAN
E-3 SCALE: 1" = 40'-0"

GRAPHIC SCALE



THIS WORK WAS PREPARED BY ME OR UNDER MY SUPERVISION
EXP 4-30-24
Michele N. Adolpho
ECS, INC.

REVISION	DATE	DESCRIPTION	BY	APPROVED
STATE OF HAWAII DEPARTMENT OF TRANSPORTATION HARBORS DIVISION				
JOB TITLE REPAIR LIGHT POLES AND PEDESTALS AT NAWILIWILI HARBOR, KAUAI, HAWAII				
SHEET TITLE PIER 2 ELECTRICAL SITE PLAN				
DESIGNED BY: MA				SHEET
DRAWN BY: CAD				E-3
CHECKED BY: MA				10 of 17 SHEETS
DATE: 04/2023	JOB NUMBER			
SCALE: AS SHOWN	S70146			