INDEX TO DRAWINGS		
SHEET NO.	DESCRIPTION	
1	TITLE SHEET	
2	STANDARD PLANS SUMMARY	
3 - 5	GENERAL NOTES FOR CONSTRUCTION	
6 - 8	WATER POLLUTION & EROSION CONTROL NOTES	
9	LEGEND AND ABBREVIATIONS	
10	TYPICAL ROADWAY SECTIONS	
11	DEMOLITION PLAN - WAIMEA CANYON DRIVE	
12	ROADWAY PLAN - WAIMEA CANYON DRIVE	
13	GRADING AND DRAINAGE PLAN - WAIMEA CANYON DRIVE	
14	PAVEMENT MARKING LEGEND DETAILS, NOTES AND SUMMARY	
15 - 17	SIGNING AND STRIPING PLAN - WAIMEA CANYON DRIVE	
18	A.C. CURB & STRIPING PLAN - MENEHUNE ROAD / HALEPULE ROAD	
19 - 20	STRIPING AND SIGNAGE DETAILS	
21	EROSION CONTROL PLAN	
22	EROSION CONTROL DETAILS	
23	TRAFFIC SIGNAL NOTES AND LEGEND	
24 - 25	TRAFFIC SIGNAL PLAN	
26 - 27	TRAFFIC SIGNAL DETAILS	
28	STREET NAME SIGN DETAILS	
29	INTERSECTION DETAILS	
30 - 32	TYPICAL TRAFFIC CONTROL PLAN AT INTERSECTION AND SHOULDER	
33	CROSS SECTIONS - WAIMEA CANYON DRIVE	

## STATE OF HAWAII

## DEPARTMENT OF TRANSPORTATION


HIGHWAYS DIVISION HONOLULU, HAWAII

## PLANS FOR

## KAUMUALII HIGHWAY INTERSECTION **IMPROVEMENTS** AT WAIMEA CANYON DRIVE AND MENEHUNE ROAD/HALEPULE ROAD PROJECT NO. 50B-01-14

DISTRICT OF WAIMEA ISLAND OF KAUA'I


34	ELECTRICAL SYMBOL LIST AND NOTES
35 - 37	NOTES (ELECTRICAL AND
	COMMUNICATION UTILITIES)
38	ELECTRICAL PLAN
39 - 43	ELECTRICAL DETAILS
44	ILLUMINATION CALCULATIONS

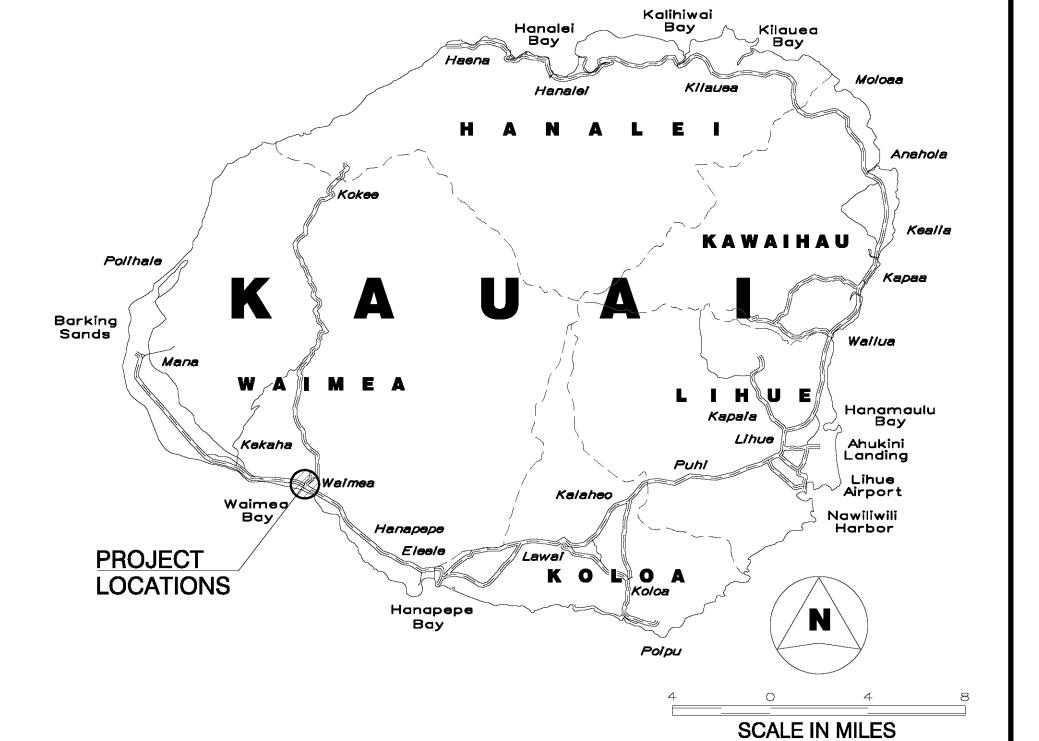

FEDERAL AID PROJECTS PREVIOUSLY CONSTRUCTED OR UNDER CONSTRUCTION

STATE OF HAWAII

- MILE POST <u>22.75</u> TO MILE POST <u>22.82</u> (RTE. 50)
- 2 MILE POST 23.02 TO MILE POST 23.16 (RTE. 50)

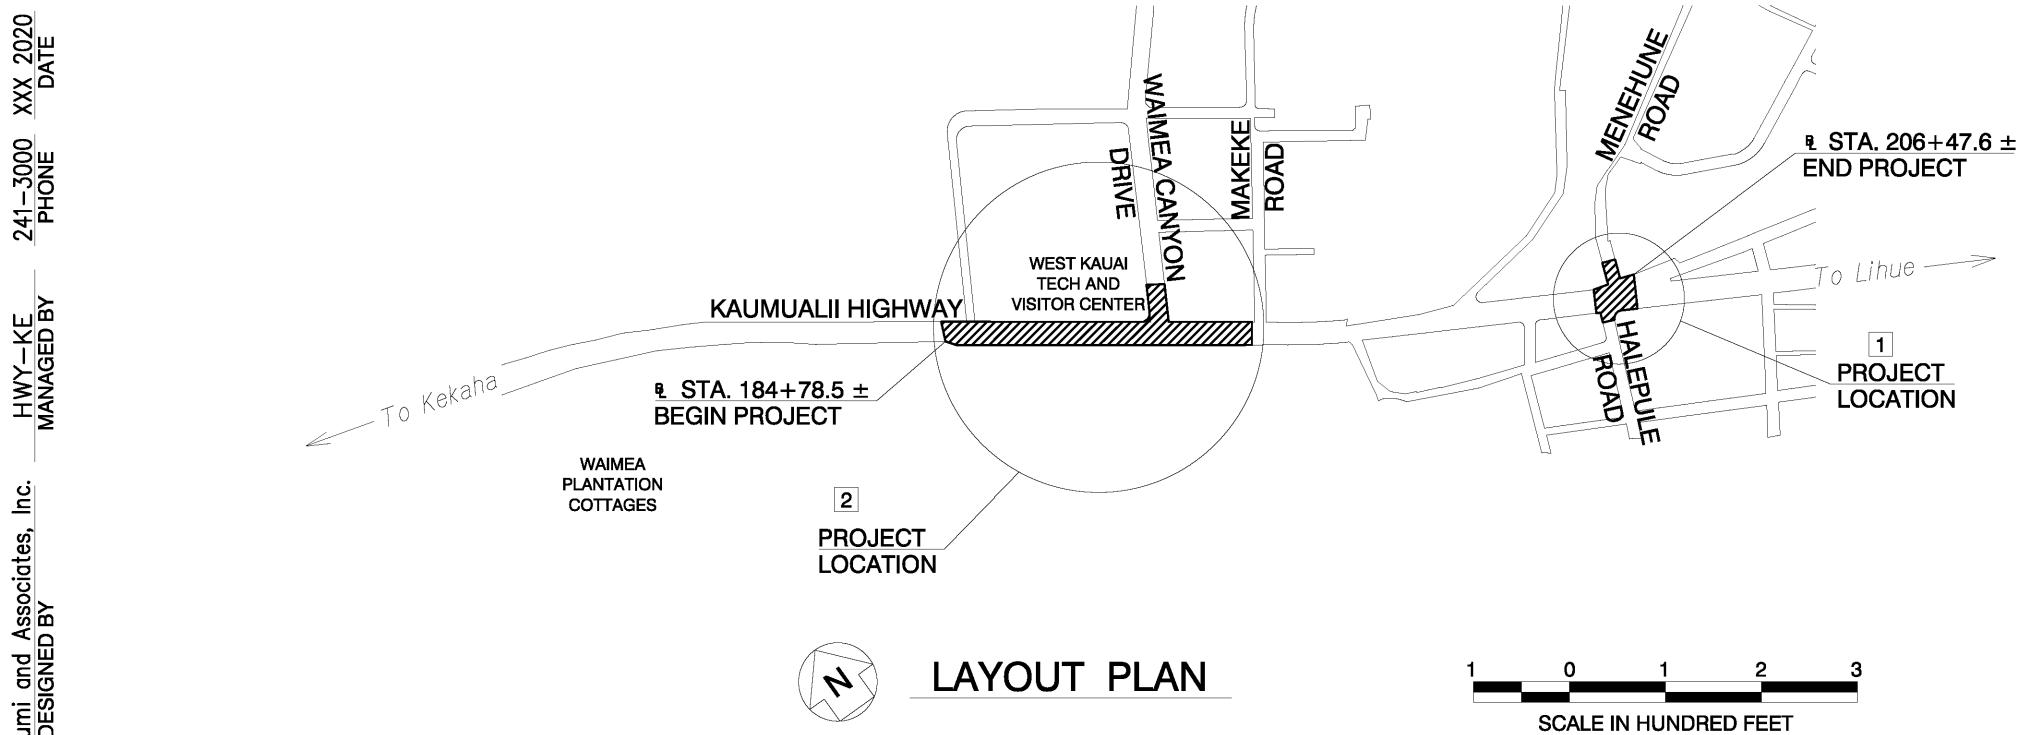

GROSS LENGTH OF PROJECT . . . . . . . 0.41 MILES NET LENGTH OF PROJECT . . . . . . . . . . . 0.21 MILES

DEPARTMENT OF TRANSPORTATION STATE OF HAWAII APPROVED:

Apr 30, 2020 DIR. OF TRANSPORTATION

DATE