


FED. ROAD DIST. NO.	STATE	PROJ. NO.	FISCAL YEAR	SHEET NO.	TOTAL SHEETS
HAWAII	HAW.	HWY-M-ART18-01	2022	63	80

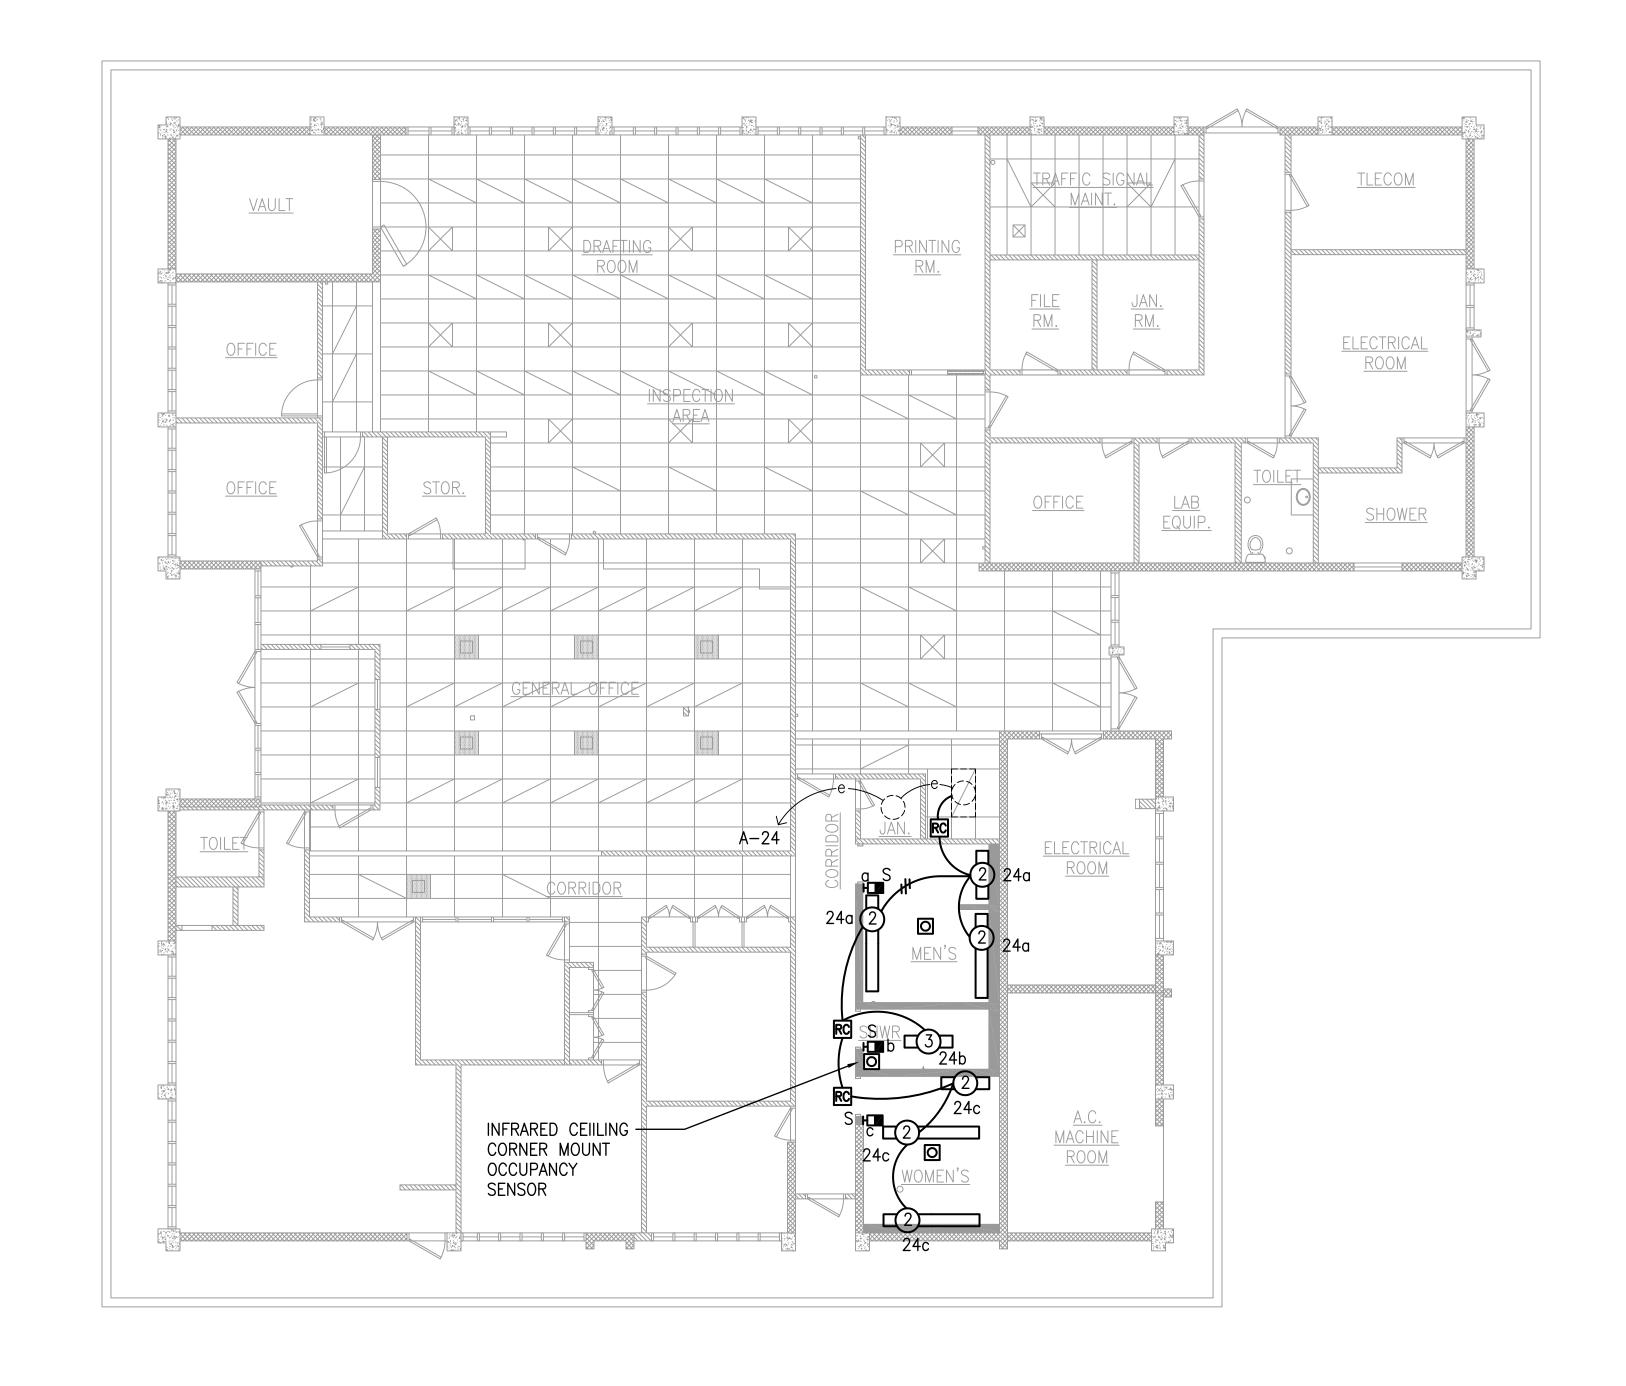

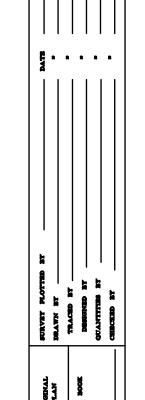

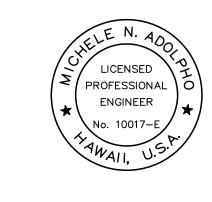



PARTIAL LIGHTING PLAN — EXISTING OFFICE BUILDING

STATE OF HAWAII DEPARTMENT OF TRANSPORTATION

PROJECT ENGINEER for ECS, Inc.

Scale: AS SHOWN

MAUI DISTRICT BASEYARD
Project No. HWY-M-ART18.01

Date: MAY 2022 SHEET No. E6 OF 80 SHEETS

5' 0 5' 10' 15' 20' 25'