


FED. ROAD STATE


FISCAL SHEET YEAR NO.


PROJ. NO.

HAW. HWY-M-ART18-01 2022 53

PIPE THRU EXTERIOR AND GRADE WALL DETAIL NOT TO SCALE

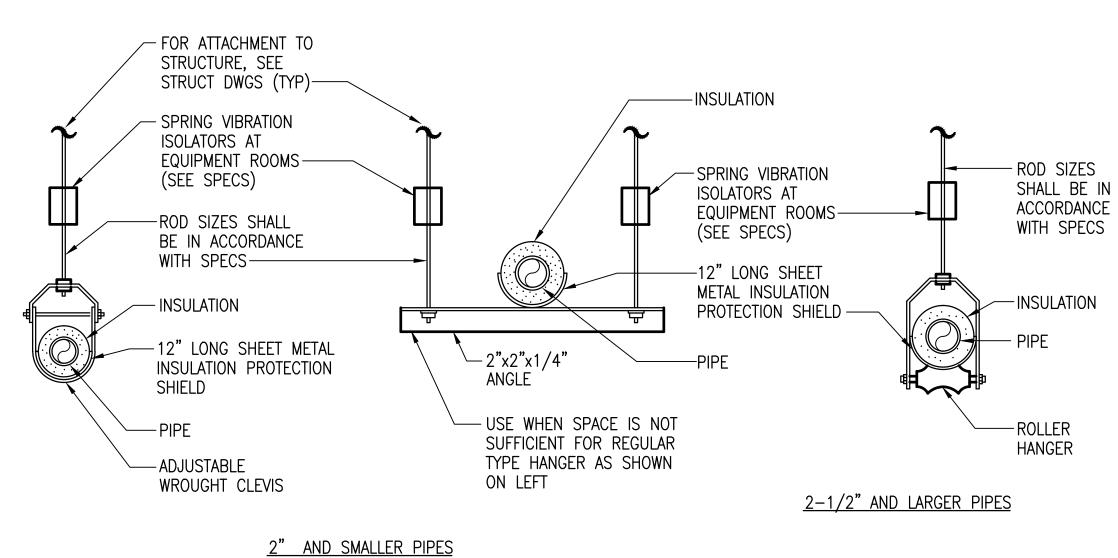

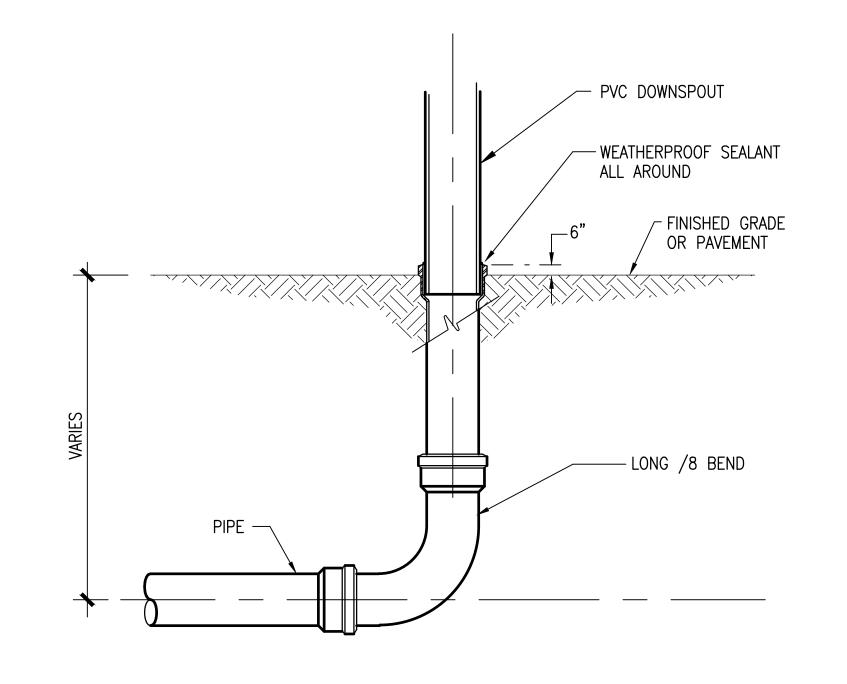

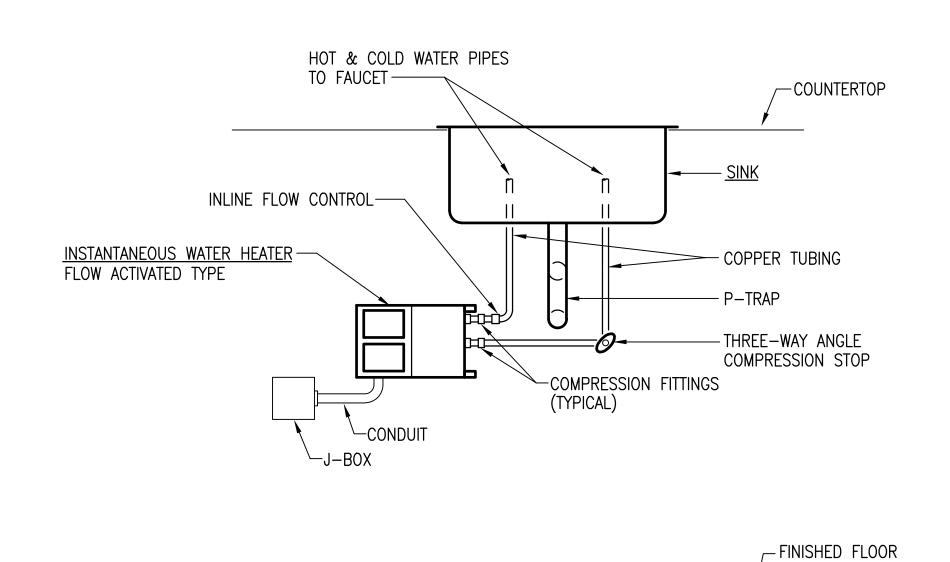


TYPICAL INSTANTANEOUS WATER HEATER DETAIL Р3 NOT TO SCALE

18" LONG RIGID INSULATION SHALL BE USED AT HANGERS.

PIPE HANGER DETAIL NOT TO SCALE

TYPICAL DOWNSPOUT CONNECTION DETAIL NOT TO SCALE Р3

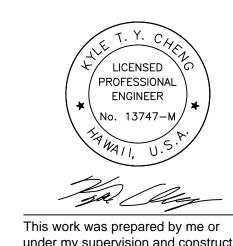

HIGHWAYS DIVISION PLUMBING DETAILS MAUI DISTRICT BASEYARD

STATE OF HAWAII DEPARTMENT OF TRANSPORTATION

Project No. HWY-M-ART18.01 Scale: N.T.S. Date: MAY 2022

SHEET No. P3 OF 79 SHEETS

ATE SURVEY PLOTT
DRAWN BY_____
TRACED BY____
DESIGNED BY___
QUANTITIES BY
CHECKED BY___

under my supervision and construction of the project will be under my observation. Expiration date 04/30/24.