



FED. ROAD DIST. NO.	STATE	FED. AID PROJ. NO.	FISCAL YEAR	SHEET NO.	TOTAL SHEETS
HAWAII	HAW.				

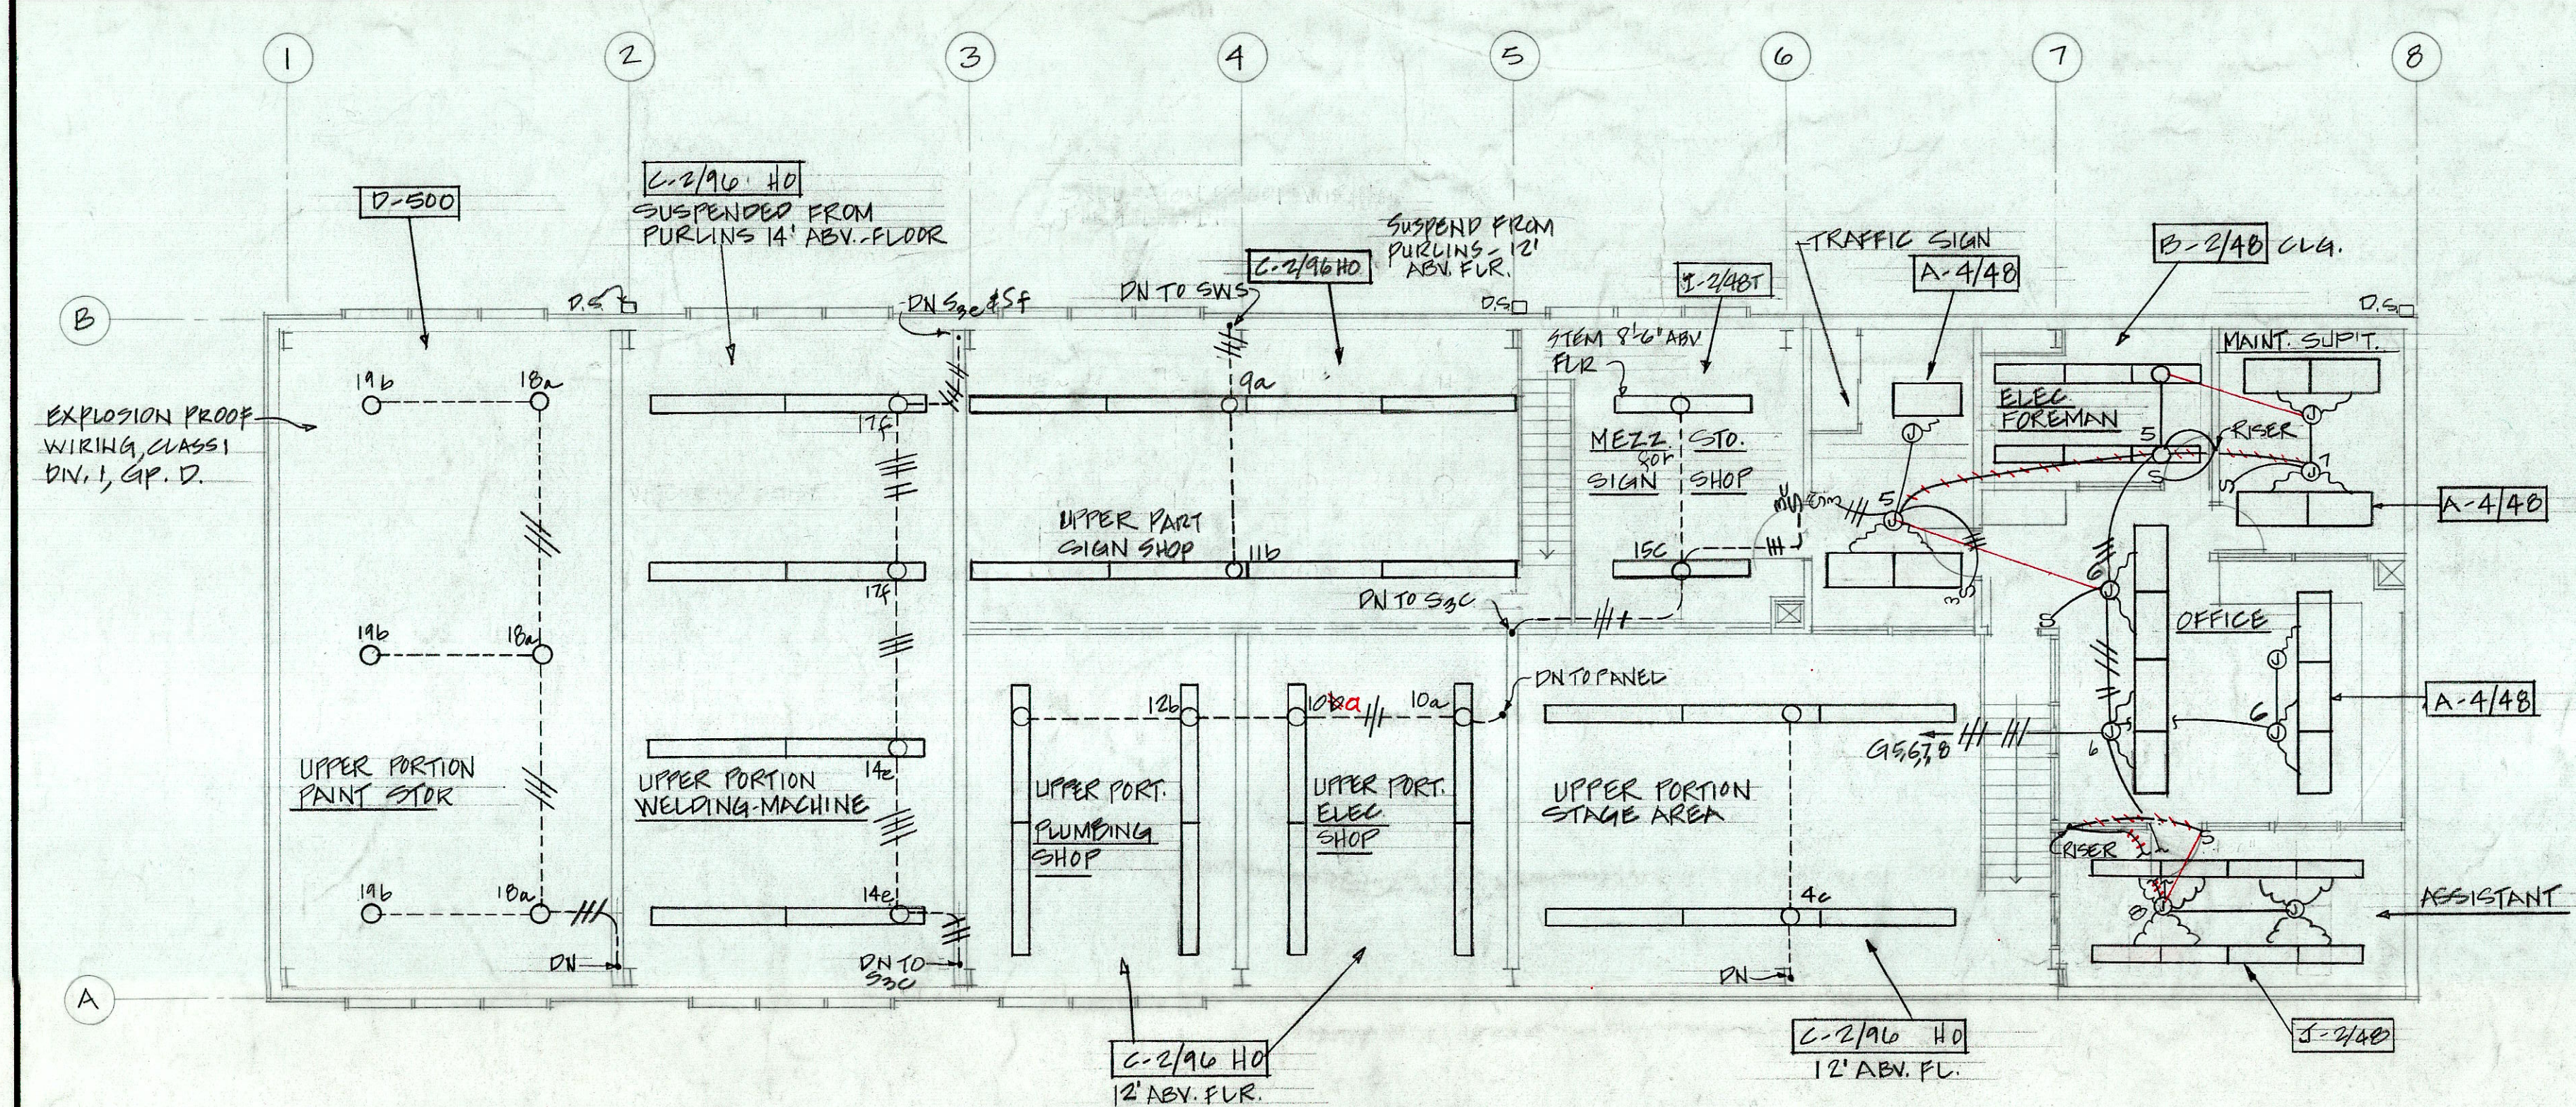

MEZZANINE FLOOR LIGHTING PLAN
SCALE: 1/8"=1'-0"

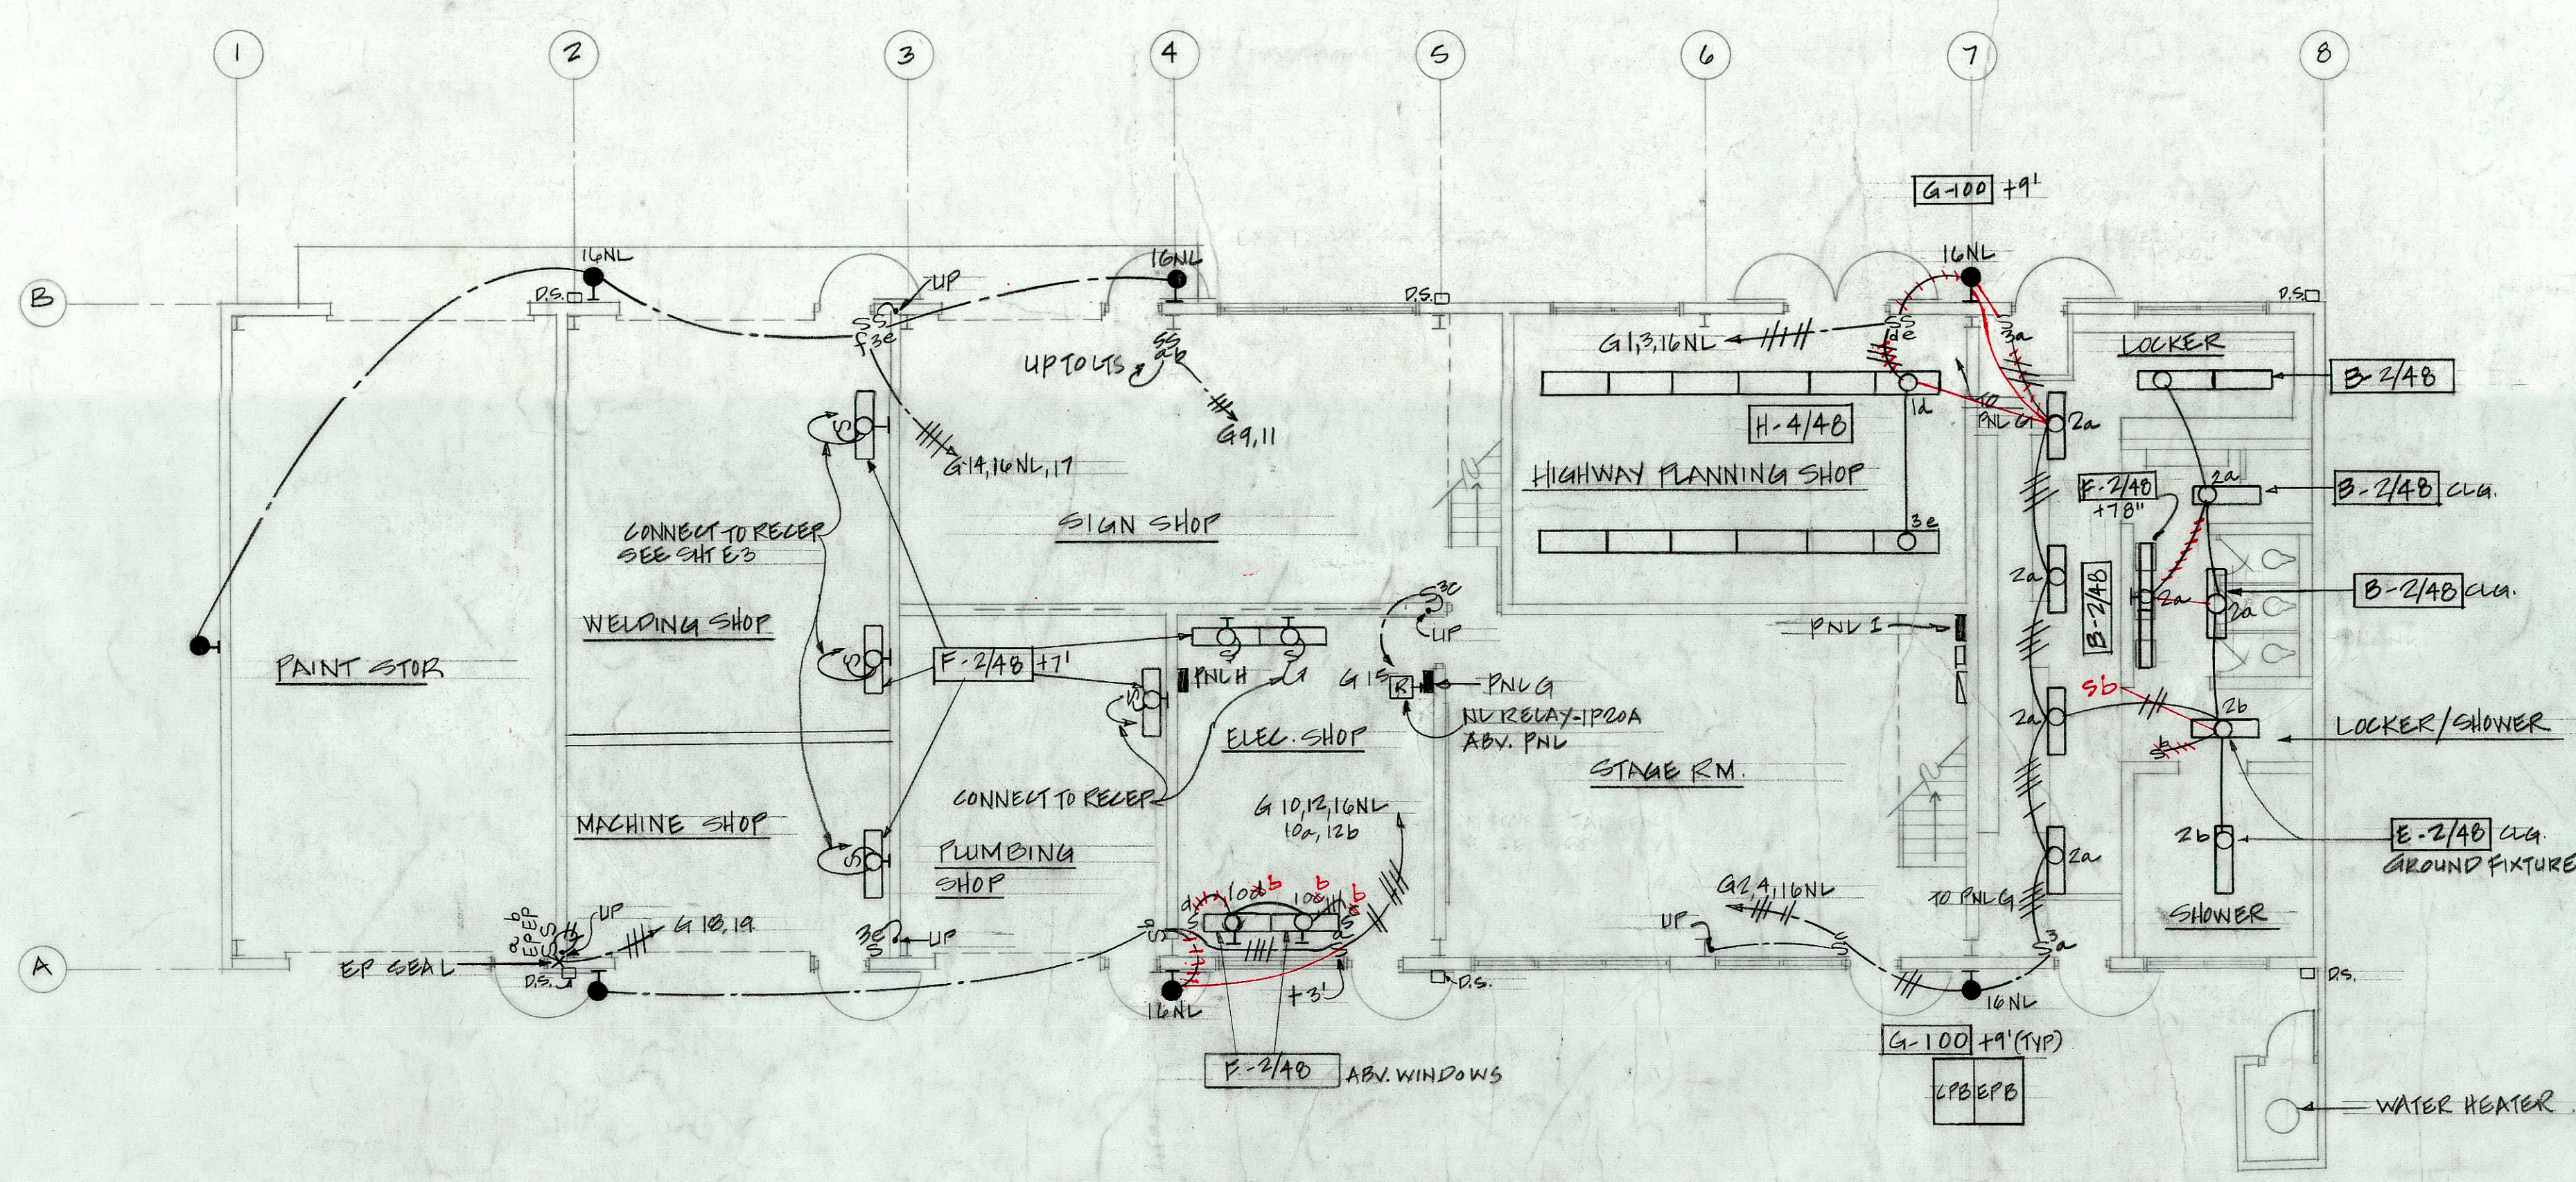

FIRST FLOOR LIGHTING PLAN
SCALE: 1/8"=1'-0"

LUMINAIRE SCHEDULE			
TYPE	LAMP	DESCRIPTION	MANUFACTURER
A-4/48	4-40W. C.W.	RECESSED FLUORESCENT LAY-IN TROFFER, 5" HIGH, K12 CLEAR PRISMATIC ACRYLIC LENS, EXTRUDED ALUMINUM FRAME AND TRIM, 2'x4', A SOUND RATED BALLAST.	DAYBRITE NOVI COLUMBIA 5000 SERIES GLOBE SUNBEAM 9220 SERIES
B-2/48	2-40W.	CEILING FLUORESCENT, EXTRUDED VIRGIN ACRYLIC PRISMATIC WRAP-AROUND LENS, SWINGS FROM EITHER SIDE FOR RELAMPING, 12" WIDE x 48" LONG.	SILVRAY TIEMPO SUNBEAM 7450 SERIES GLOBE Y3850 DAYBRITE MARKSMAN LIGHTOLIER PRISMALINE
C-2/96HO	2-96" 800MA	INDUSTRIAL, PORCELAIN REFLECTORS, 15% UPWARD COMPONENT, DEEP V EMBOSSED & RIBBED, TURNED EDGES, 30"x30" BAKED WHITE METAL LOUVERS, SWIVEL BALL ALIGNER, STEM MOUNTED.	SYLVANIA PV-10 DAYBRITE CF1-10 MILLER-CROWN
D-500	500W.	EXPLOSION PROOF, CLASS I, DIVISION 1, GROUP D, RLM STANDARD DOME REFLECTOR, GLASS GLOBE AND GUARD, SUSPENSION MOUNTING	CROUSE HINDS EVA 2064 KILLARK APPLETON
E-2/48	2-40W. C.W.	VAPOR PROOF FLUORESCENT, CEILING, IMPACT RESISTANT PLASTIC OR FIBERGLASS CHASSIS, VIRGIN ACRYLIC PLASTIC LENS, WATERTIGHT GASKETS WITH CORROSION RESISTANT LATCHES.	DAYBRITE VAPORLUME SYLVANIA SENTRY WAKEFIELD ON-214
F-2/48	2-40W. C.W.	WALL FLUORESCENT, BAKED WHITE ENAMEL FINISHED 20 GAGE STEEL CHASSIS, EXTRUDED PRISMATIC PLASTIC LENS.	DAYBRITE 45242-4 SUNBEAM MARCO DEVINE B-349
G-100	100W. H38 MERCURY	WALL BRACKET MERCURY, DIE CAST ALUMINUM HOUSING, PRESSED PRISMATIC ENDURAL REFRACTOR, ASY-METRIC REFLECTOR, METALLIC BRONZE FINISH	HOLOPHANE 410 STONCO 511-100MM
H-4/48	4-40W.	SIMILAR TO TYPE B EXCEPT 4 LAMPS AND 18" WIDE.	
I-2/48T	4-40W	FLUORESCENT STRIP WITH GALV. WIRE GUARD, SWIVEL BALL ALIGNERS	SMOOT HOLMAN SUNBEAM WESTINGHOUSE
J-2/48	2-40W	SIMILAR TO TYPE A EXCEPT 1'x4'	

DATE	
DESIGNED BY	
DRAWN BY	
CHECKED BY	
NOTED BY	
NO.	

PRINTED ON NO. 1000M CLEARPRINT

DATE: OCT. 12, 1971

STATE OF HAWAII
DEPARTMENT OF TRANSPORTATION
HIGHWAYS DIVISION
OAHU DISTRICT BASEYARD MAINTENANCE BUILDING
SHAFTER FLATS INDUSTRIAL DEVELOPMENT
AT MOANALUA, HONOLULU, OAHU, HAWAII

LIGHTING PLANS AND LUMINAIRE SCHEDULE

HERBERT Y. MATSUMURA & ASSOCIATES, INC.
871 KAPIOLANI BLVD. HONOLULU, HAWAII

SHEET No. E2 OF 2 SHEETS

ALBERT S. C. CHONG
REGISTERED PROFESSIONAL ENGINEER
No. 1003
HAWAII, U.S.A.

THIS WORK WAS PREPARED BY ME
OR UNDER MY SUPERVISION

Albert S. C. Chong, PE

