




NOTES:

1. CIRCUIT ASSIGNMENTS SHOWN ON PLAN REFLECT THE PANEL A BREAKER ASSIGNMENT. SEE PANEL SCHEDULE FOR ADDITIONAL INFORMATION.
2. EXISTING RECEPTACLES TO REMAIN WHICH HAVE BEEN IDENTIFIED WITH A CIRCUIT ASSIGNMENT ON THE ELECTRICAL PLAN SHALL BE PROVIDED WITH UPDATED LABELS SPECIFYING THE NEW CIRCUIT ASSIGNMENT BASED OFF THE PANEL A BREAKER ASSIGNMENT.

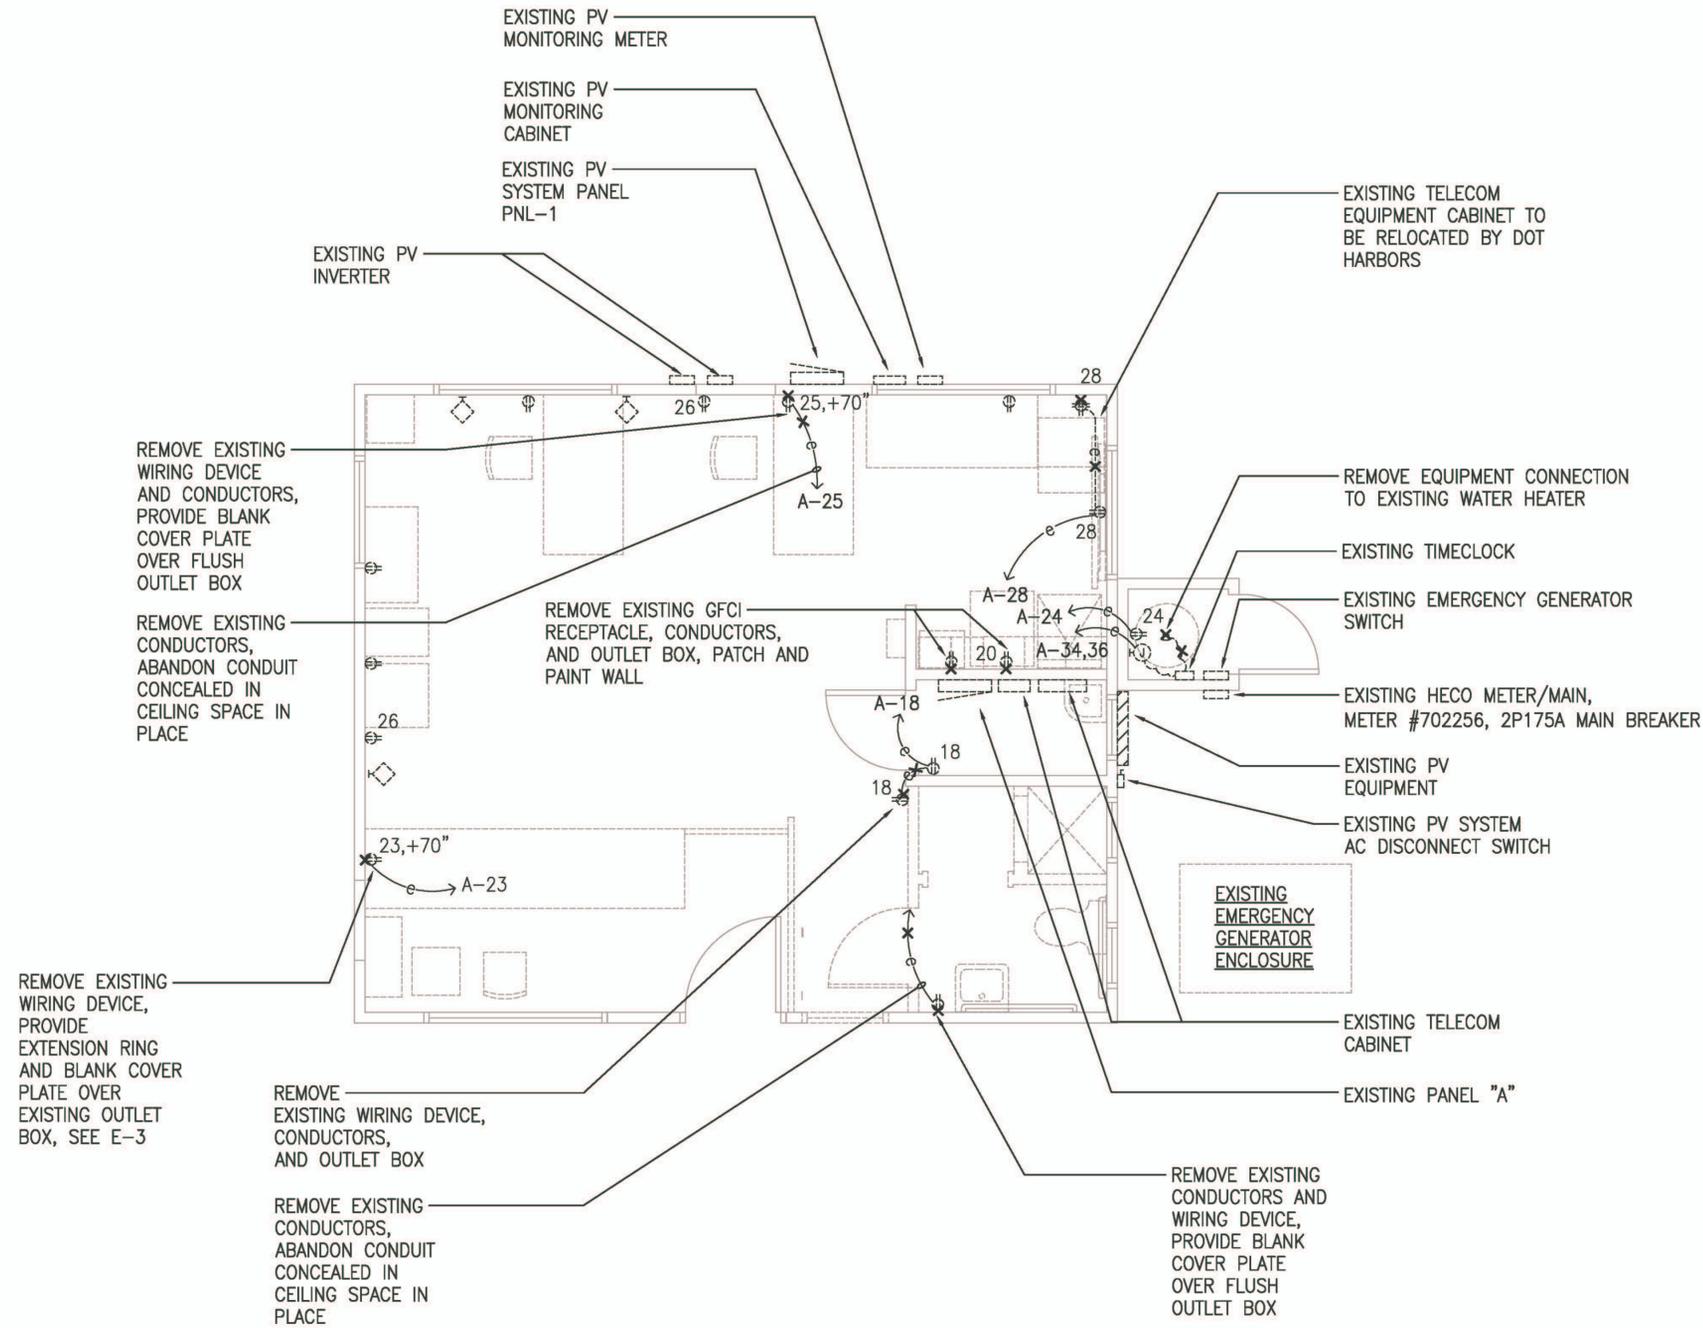

1 ELECTRICAL DEMOLITION FLOOR PLAN
E-2 SCALE: 3/8" = 1'-0"

 GRAPHIC SCALE

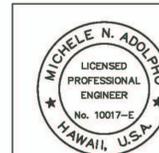

THIS WORK WAS PREPARED BY ME OR UNDER MY SUPERVISION

Michele N. Adellechio
 PROJECT ENGINEER FOR
 ECS, INC.
 APRIL 30, 2024
 EXPIRATION DATE OF LICENSE

REV	DATE	DESCRIPTION	BY	APPROVED
STATE OF HAWAII DEPARTMENT OF TRANSPORTATION HARBORS DIVISION				
JOB TITLE REPAIR HARBOR AGENT'S OFFICE AT KALAELOA BARBERS POINT HARBOR KALAELOA BARBERS POINT HARBOR, OAHU, HAWAII				
SHEET TITLE ELECTRICAL DEMOLITION PLAN				
DESIGNED BY:	JC			SHEET
DRAWN BY:	OL			E-2
CHECKED BY:	MA			
DATE:	JAN. 2023	JOB NUMBER		
SCALE:	AS NOTED	S10846		