### **INDEX TO DRAWINGS** SHEET NO. **DESCRIPTION** TITLE SHEET 2 - 3 **DETAILED INDEX** STANDARD PLANS SUMMARY 5 - 15 **NOTES** LOCATION MAPS 16 - 17 18 - 30 **DETAILS** 31 - 149 CIVIL PLANS TYPICAL TRAFFIC CONTROL PLANS (1) (2) (3) (4) 150 - 155 156 - 187 **ELECTRICAL PLANS** Plan Sht. Nos. 155S-1, 2155S-2, 3155S-3, and 4155S-4 are supplementary sheets to this project, added during Addendum & "AS-BUILT" TOTAL SHEET COUNT after Addendum & "AS-BUILT" postings is 191 sheets.


## STATE OF HAWAII


### DEPARTMENT OF TRANSPORTATION

HIGHWAYS DIVISION
HONOLULU, HAWAII
"AS-BUILT"
PLANS FOR

# FED. ROAD DIST. NO. STATE FEDERAL AID PROJ. NO. FISCAL YEAR NO. SHEETS HAWAII HAW. CMAQ-0300(92) 2004 1 187

98) 7413

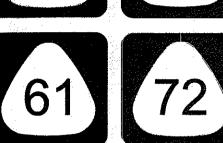


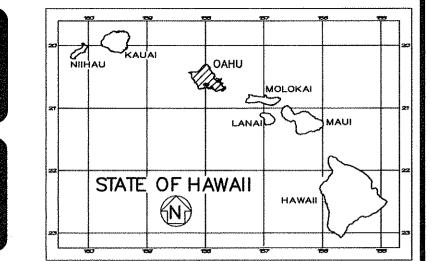

### PEDESTRIAN FACILITIES & ADA COMPLIANCE

AT VARIOUS LOCATIONS ON OAHU, UNIT 1 FEDERAL AID PROJECT NO. CMAQ-0300(92)

DISTRICTS OF HONOLULU AND KOOLAUPOKO ISLAND OF OAHU

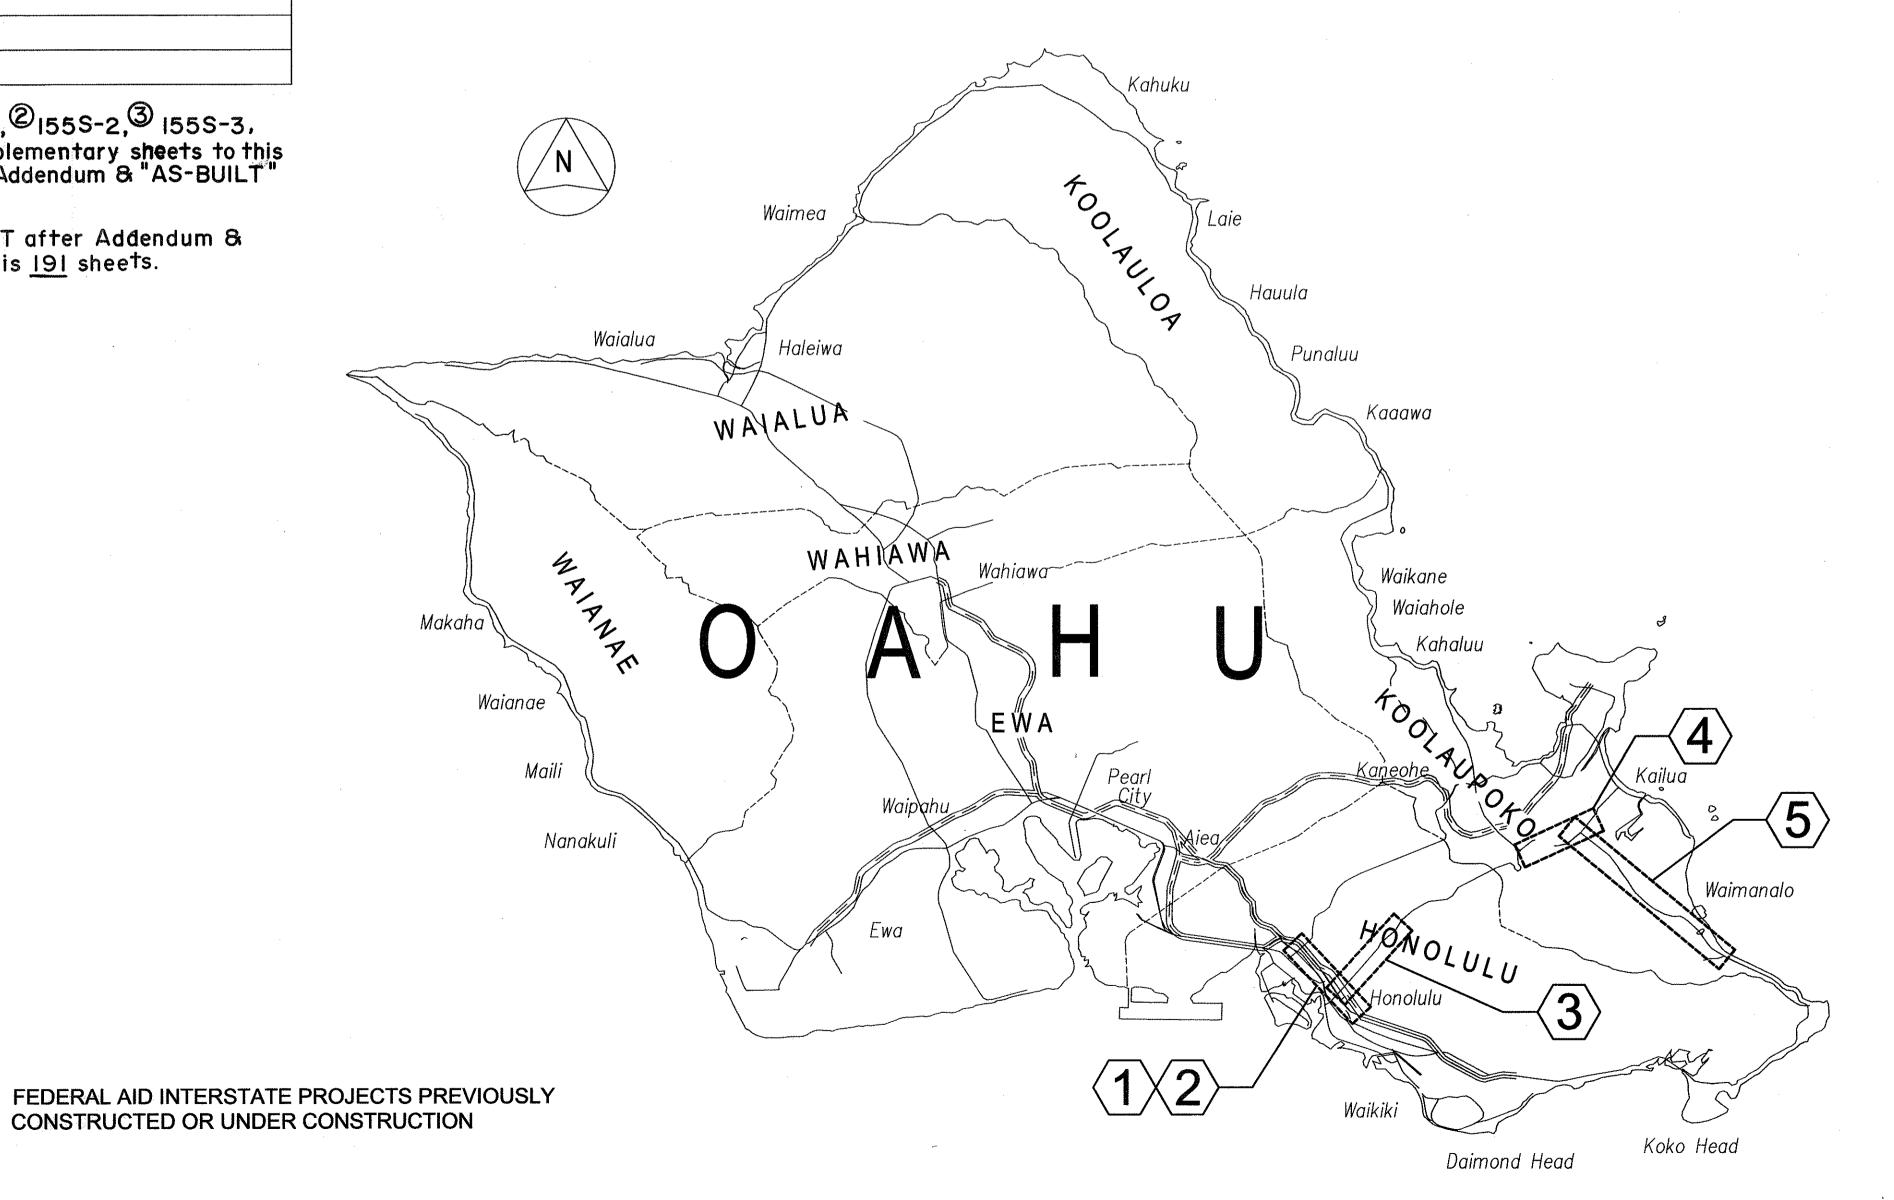

#### PROJECT SITES

- 1 Vineyard Boulevard, Route 98

  MILE POST 0.20 TO MILE POST 1.36
- 2 Liliha Street, Route 7413
  MILE POST 0.00 TO MILE POST 0.34
- Pali Highway, Route 61

  MILE POST 0.00 TO MILE POST 4.28
- Pali Highway, Route 61

  MILE POST 8.94 TO MILE POST 10.10
- (5) Kalanianaole Highway, Route 72 MILE POST 0.00 TO MILE POST 5.35

CHANGES MADE DURING CONSTRUCTION HAVE BEEN INCORPORATED ON THESE PLANS EXCEPT CHANGES IN THE ORIGINAL THEORETICAL QUANTITIES. FOR ACTUAL QUANTITIES, REFER TO PROJECT LEDGER AND/OR COMPUTATION BOOK.

Marin C. H. Judfield
RESIDENT ENGINEER

3-28-2008 DATE

DEPARTMENT OF TRANSPORTATION STATE OF HAWAII

APPROVED:

DIR. OF TRANSPORTATION

DATE