


FED. ROAD DIST. NO.	STATE	FED. AID PROJ. NO.	FISCAL YEAR	SHEET NO.	TOTAL SHEETS
HAWAII	HAW.	STP-0300(66)	1998	1	

ELECTRICAL SYMBOLS

- EXISTING STREET LIGHT ON WOOD POLE
- REMOVE EXISTING STREET LIGHT LUMINAIRE & BRACKET ARM
- EXISTING STREET LIGHT ON CONCRETE BASE
- REMOVE EXISTING STREET LIGHT POLE. DEMOLISH CONCRETE BASE 24" BELOW FINISH GRADE
- NEW 250W HPS STREET LIGHT STANDARD & CONCRETE BASE. SEE DET

A
- NEW 2" PVC CONDUIT
- EXISTING CONDUIT TO BE REUSED, REPLACE EXISTING CONDUCTORS WITH 2#8 RHW-USE & 1#8 GROUND
- DENOTES REFERENCE TO MATERIAL LIST ITEM No. SEE SHEET E11 FOR LISTING

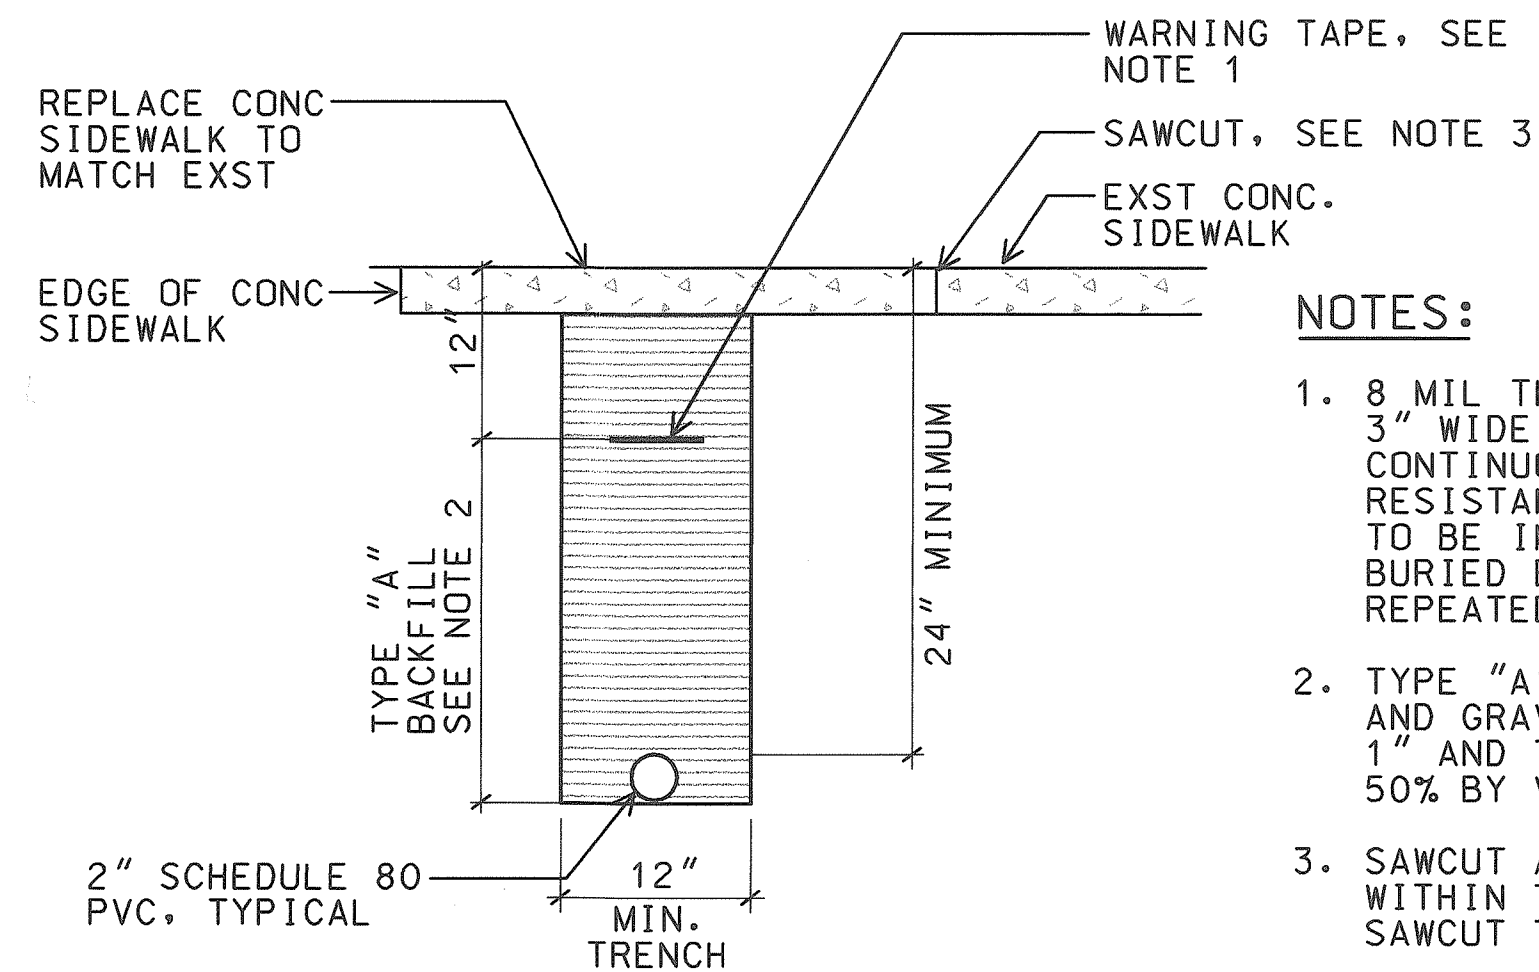

A

E1

 DIRECT BURIED CONDUIT (UNDER CONC. SIDEWALK) NTS 98058LDE


NOTES:

- 8 MIL THICK RED COLORED PLASTIC WARNING TAPE 3" WIDE, ENTIRE LENGTH OF DUCT. TAPE TO HAVE CONTINUOUS METALLIC BACKING AND CORROSION RESISTANT FOIL CORE. WARNING AND IDENTIFICATION TO BE IMPRINTED ON TAPE AND SHALL READ "CAUTION BURIED ELECTRIC CABLE BELOW". MESSAGE SHALL BE REPEATED APPROXIMATELY EVERY TEN FEET.
- TYPE "A" BACKFILL: BEACH SAND, EARTH OR EARTH AND GRAVEL USED, THE MAXIMUM ROCK SIZE SHALL BE 1" AND THE MIXTURE SHALL CONTAIN NOT MORE THAN 50% BY VOLUME OF ROCK PARTICLES.
- SAWCUT AT SCORE JOINT. REPLACE CONCRETE SIDEWALK WITHIN THAT AREA. IF SCORE LINE IS LESS THAN 12", SAWCUT THE NEXT CONCRETE SLAB.

SITE ELECTRICAL PLAN

SCALE: 1"=40'-0"


98058-SA

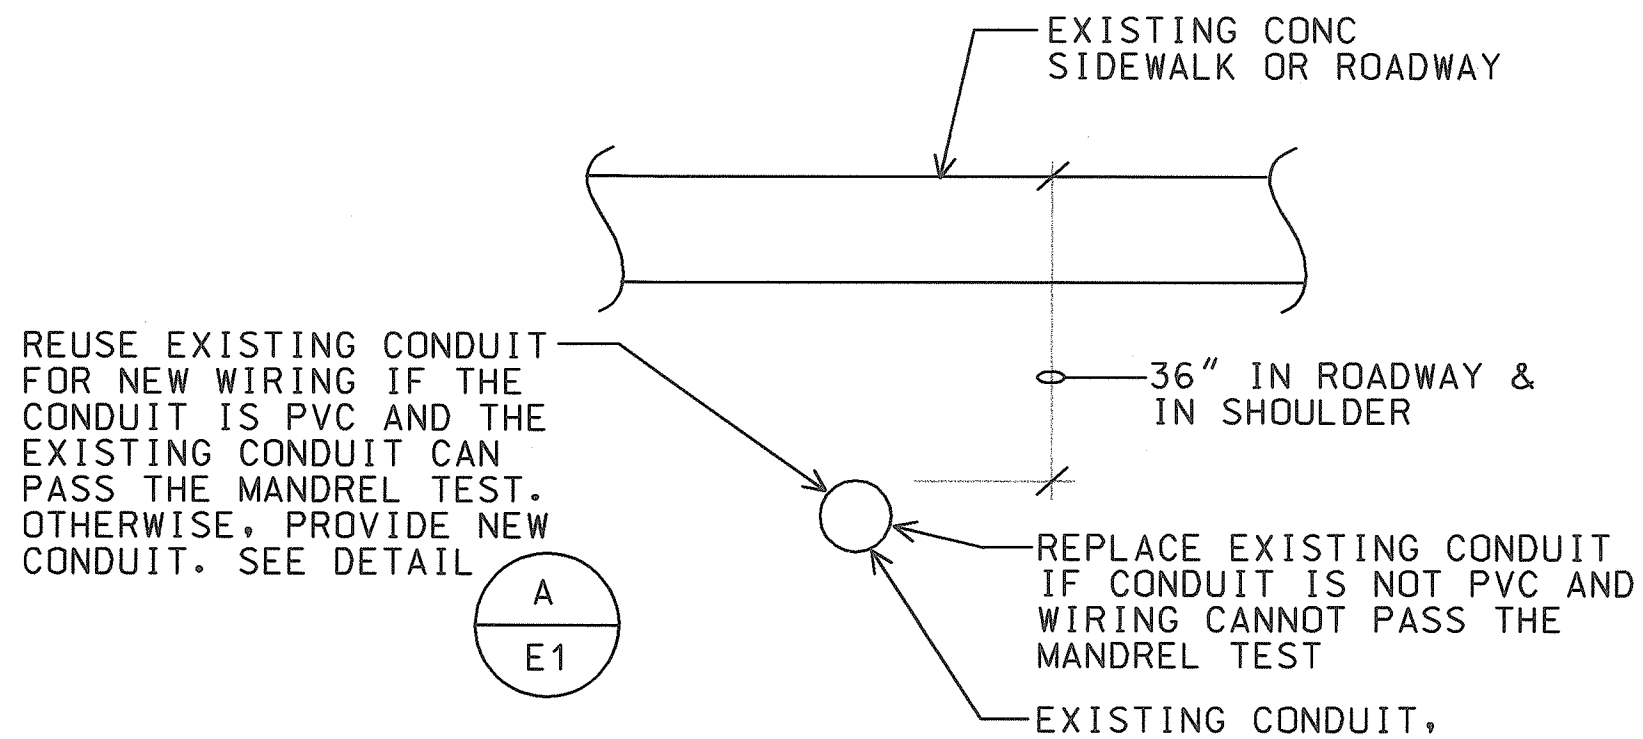

B

E1

 EXISTING DUCT SECTION NTS 98058-DB

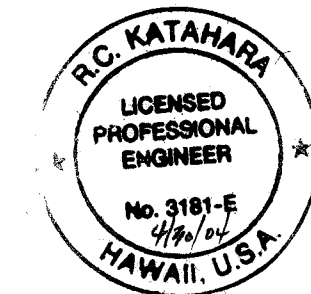


THIS WORK WAS PREPARED BY ME OR UNDER MY SUPERVISION.
R.C. KATAHARA 11/25/98
MK ENGINEERS, LTD.


DATE	REV	DESCRIPTION
8/16/99	1	REV. WARNING TAPE
STATE OF HAWAII DEPARTMENT OF TRANSPORTATION HIGHWAYS DIVISION		
SITE ELECTRICAL PLAN		
HIGHWAY LIGHTING SAFETY IMPROVEMENTS KAMEHAMEHA HIGHWAY VICINITY OF LIKELIKE HIGHWAY/KANEHOE BAY DRIVE INTERSECTION TO UALANI PLACE		
FEDERAL AID PROJ. NO. STP-0300(66)		
SCALE: AS NOTED		DATE: DECEMBER 1998
SHEET No. E1 OF 56 SHEETS		

CO-E1

FED. ROAD DIST. NO.	STATE	FED. AID PROJ. NO.	FISCAL YEAR	SHEET NO.	TOTAL SHEETS
HAWAII	HAW.	STP-0300(66)	1998	2	

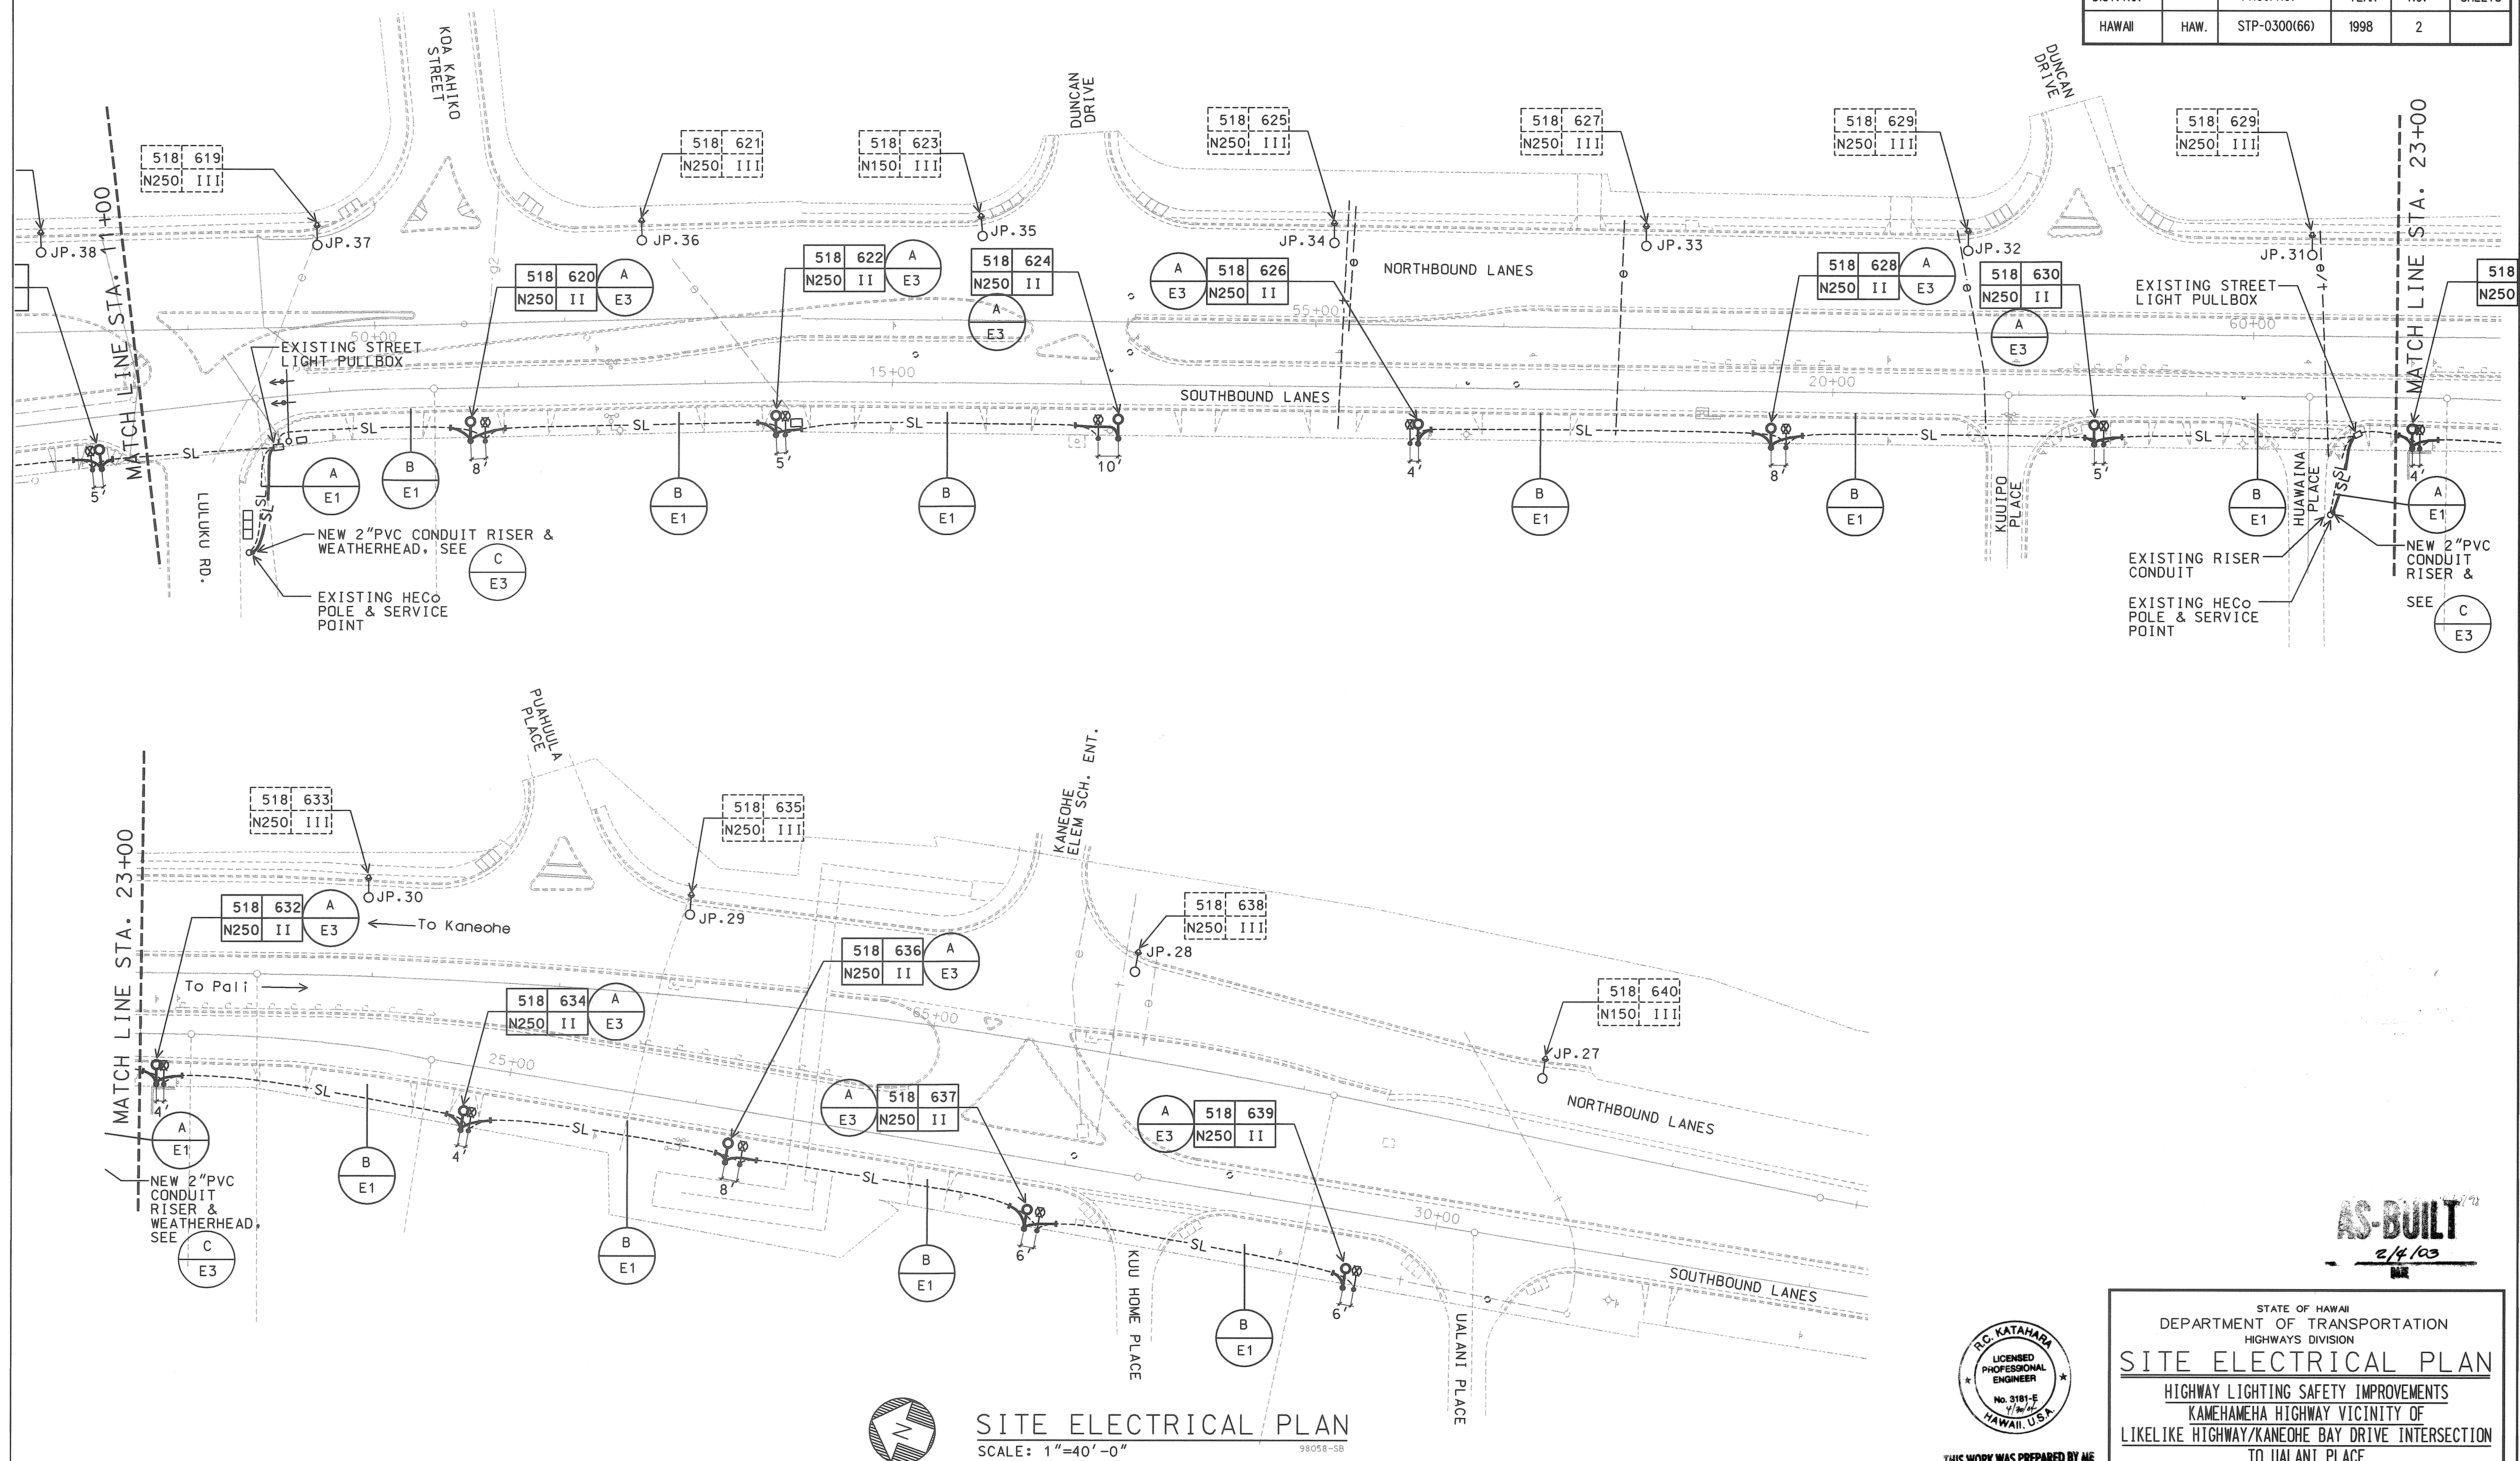

SITE ELECTRICAL PLAN
SCALE: 1"=40'-0"

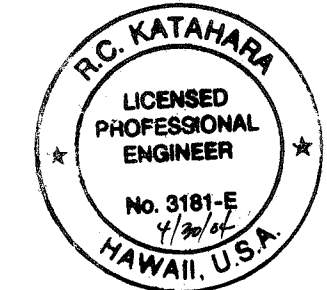

THIS WORK WAS PREPARED BY ME
OR UNDER MY SUPERVISION.
R.C. KATAHARA 11/25/98
MK ENGINEERS, LTD.

STATE OF HAWAII
DEPARTMENT OF TRANSPORTATION
HIGHWAYS DIVISION


SITE ELECTRICAL PLAN
HIGHWAY LIGHTING SAFETY IMPROVEMENTS
KAMEHAMEHA HIGHWAY VICINITY OF
LIKELIKE HIGHWAY/KANEOHE BAY DRIVE INTERSECTION
TO UALANI PLACE
FEDERAL AID PROJ. NO. STP-0300(66)

SCALE: AS NOTED DATE: DECEMBER 1998


SHEET No. **E2** OF **56** SHEETS

AS-BUILT
2/4/03



FED. ROAD DIST. NO.	STATE	FED. AID PROJ. NO.	FISCAL YEAR	SHEET NO.	TOTAL SHEETS
HAWAII	HAW.	STP-0300(66)	1998	3	

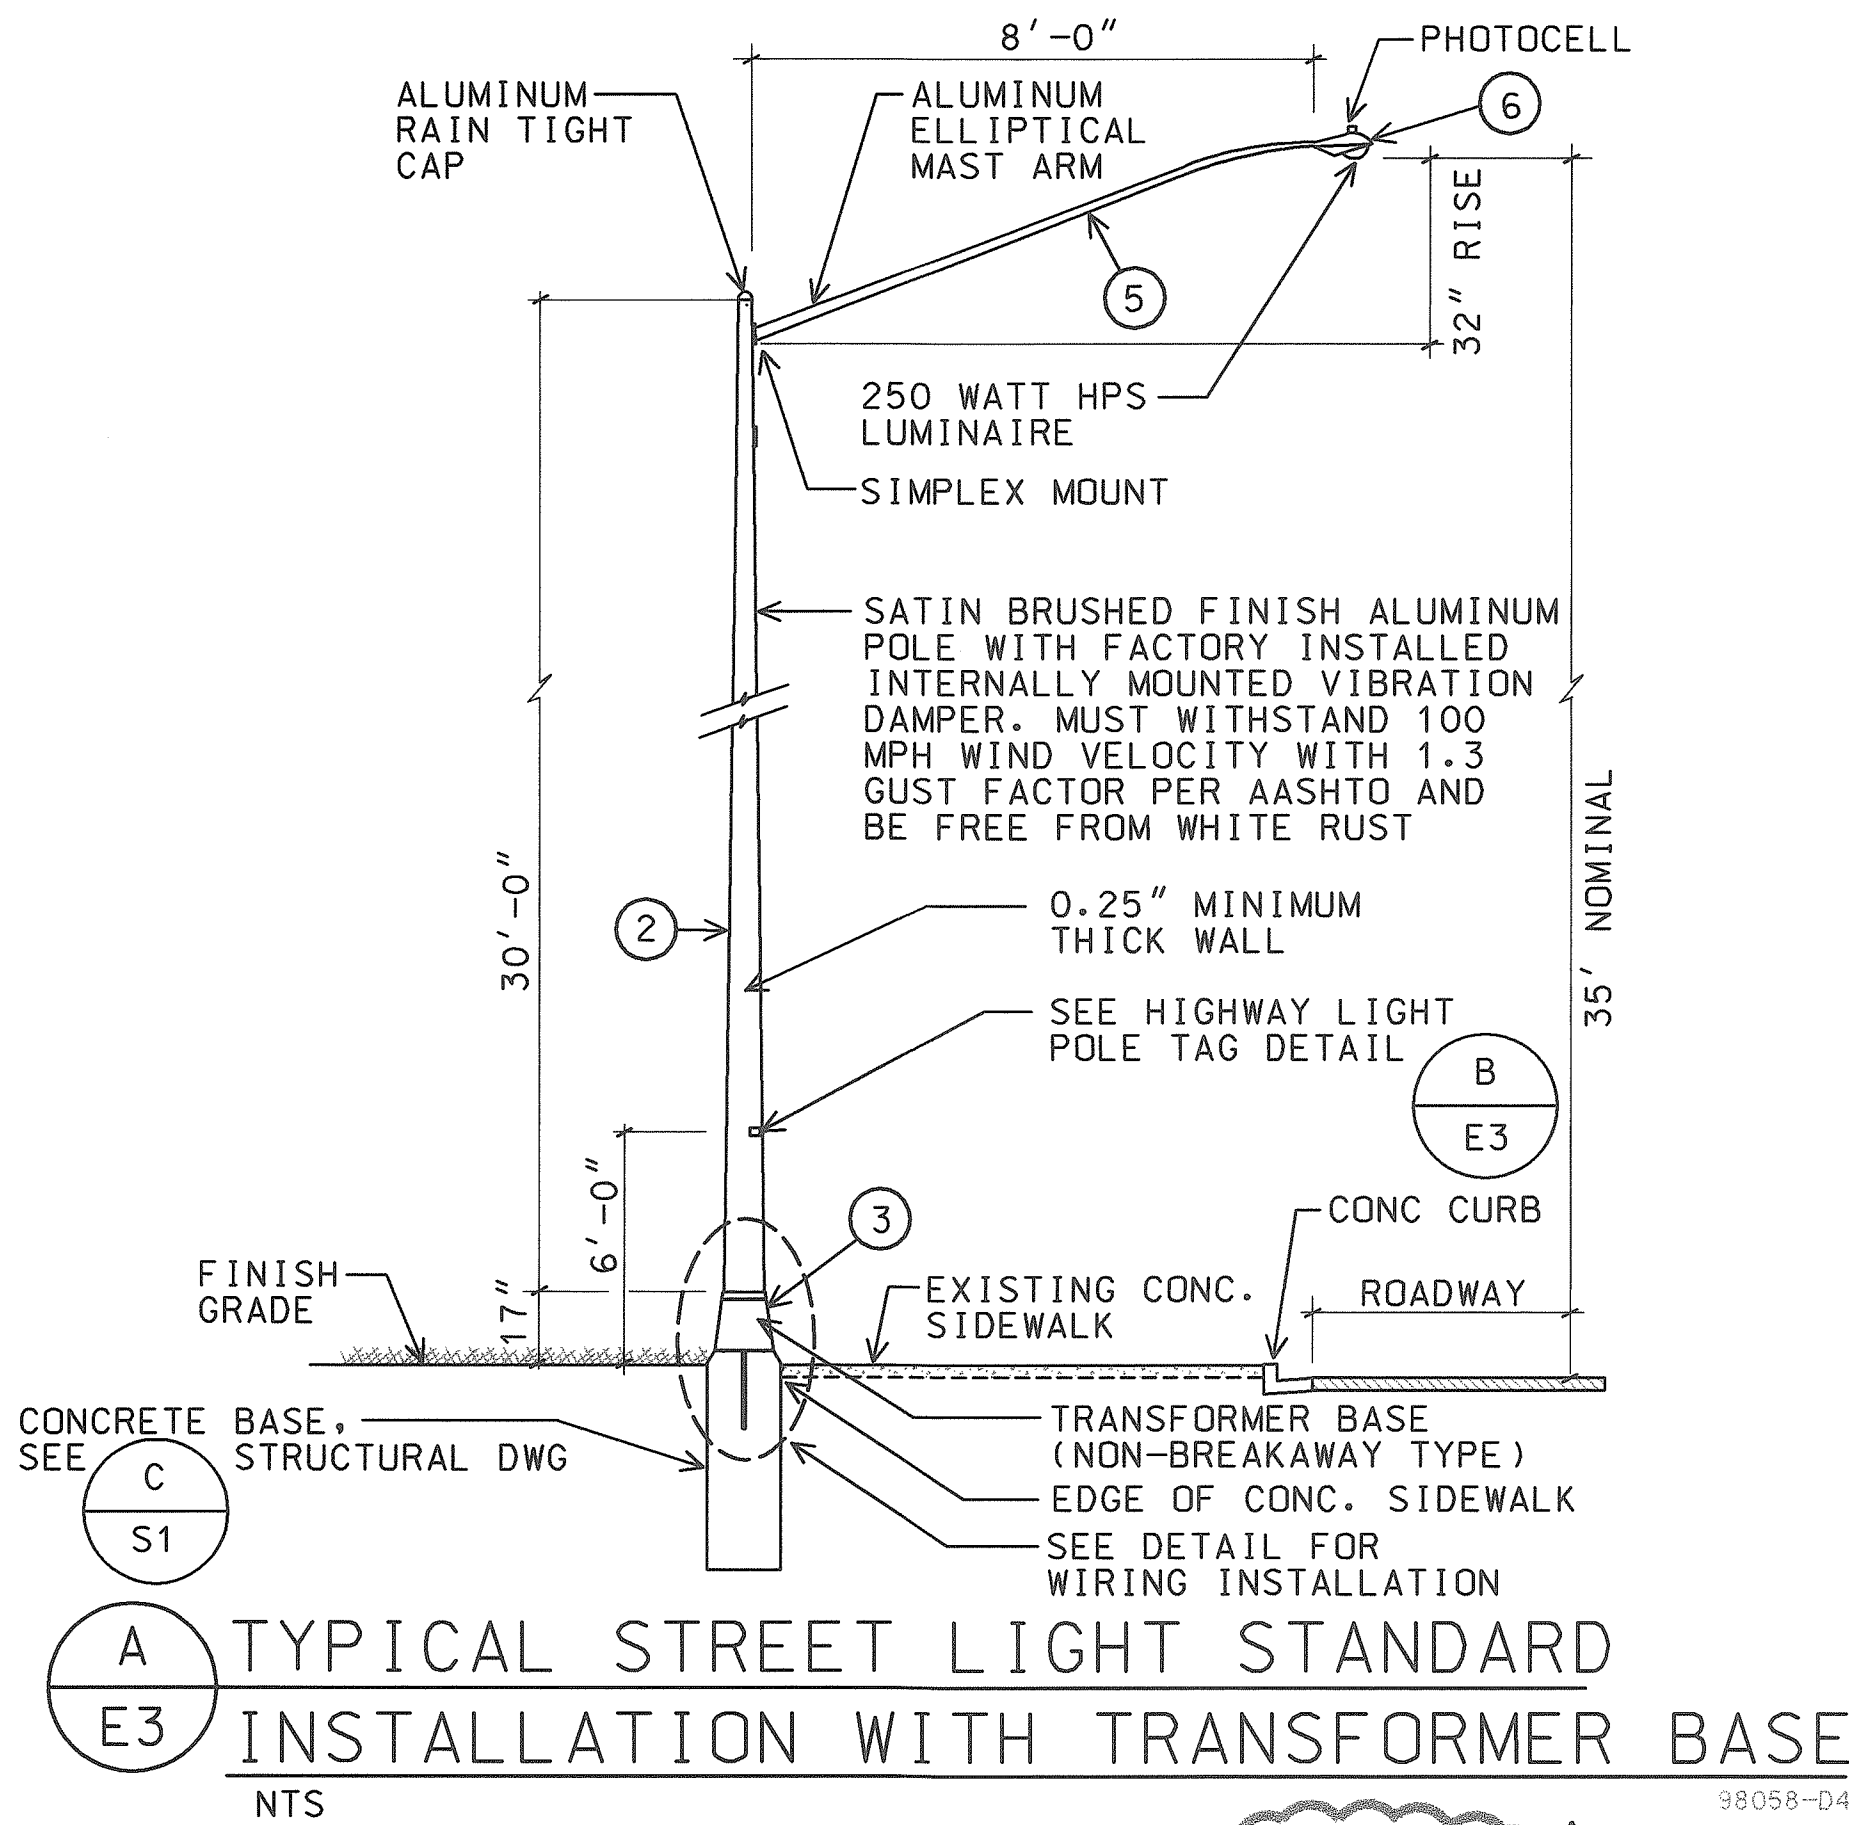

MATERIAL LIST		
ITEM	DESCRIPTION	MANUFACTURER
①	LIGHT POLE, 28', ALUM	LEXINGTON 2708-45808T4
②	LIGHT POLE, 30', ALUM	LEXINGTON 2908-45808T4
③	TRANSFORMER BASE (ALUM)	LEXINGTON 08R1012S17
④	MAST ARM, 6', ALUM, SINGLE/DOUBLE SIMPLEX MOUNT	LEXINGTON 2MA0632S
⑤	MAST ARM, 8', ALUM, SINGLE SIMPLEX MOUNT	LEXINGTON 1MA0832S
⑥	LUMINAIRE, 250W HPS	GENERAL ELECTRIC M4RR-25-S-5-M-1-G-MS2

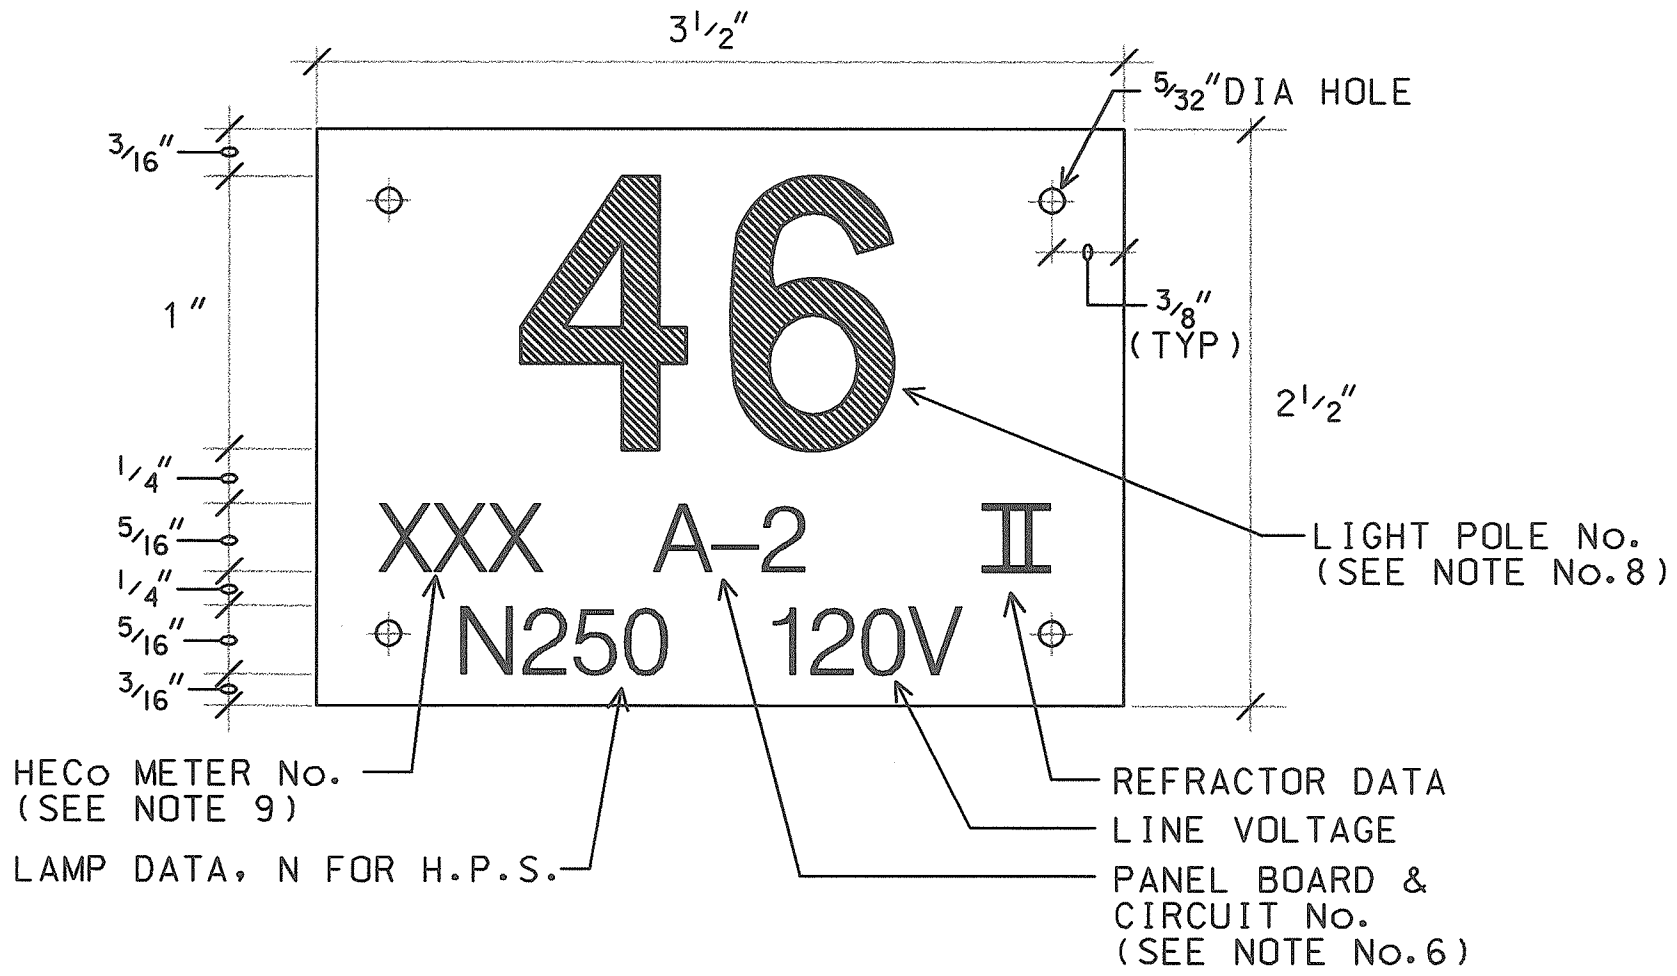

- NOTES:**
- USE 3 PLY LAMINATED FLEXIBLE PLASTIC BLACK-WHITE-BLACK THICKNESS BLACK CAP SHEET-0.010", WHITE BASE SHEET-0.052", BLACK BASE SHEET-0.010".
 - LIGHT POLE NUMBER SIZE SHALL BE 1" HIGH AND ENGRAVED 1/8" WIDE, WHITE IN COLOR (NUMBER AS REQUIRED).
 - NOMENCLATURE SIZE SHALL BE 5/16" HIGH AND ENGRAVED 1/32" WIDE, WHITE IN COLOR (HECO VAULT NUMBER PANEL BOARD AND CIRCUIT NUMBER, LINE VOLTAGE, LAMP DATA AND REFRACTOR DATA AS REQUIRED).
 - ATTACH TO ALUMINUM AND STEEL POST WITH NO. 8 STAINLESS STEEL, 1/2" LONG DRIVE SCREWS IN 1/8" DRILL HOLE. ATTACH TO WOOD POLES WITH 4D ALUMINUM NAIL.
 - NUMBERS ARE INSCRIBED BY CUTTING THROUGH "BLACK CAP SHEET" TO EXPOSE "WHITE LETTERS."
 - NOMENCLATURE REQUIRED FOR SYSTEMS WITH TWO OR MORE CIRCUITS (LETTER INDICATES PANEL BOARD, NUMBER INDICATES CIRCUIT).
 - FOR LIGHT POLES INSTALLED ON RAMP, ASSIGN NUMBERS TO INCLUDE RAMP I.D. AND LIGHT NUMBER. LEGEND MAY BE LESS THAN ONE (1) INCH IN HEIGHT.
 - LIGHT NUMBERS SHALL BE OBTAINED FROM THE STATE. USE AN ALPHABET SUFFIX TO DESIGNATE LIGHTS MOUNTED ON THE SAME POLE (e.g. 123A & 123B).
 - FOR NON-METERED SYSTEM, CALL OUT THE CONTRACT NUMBER.

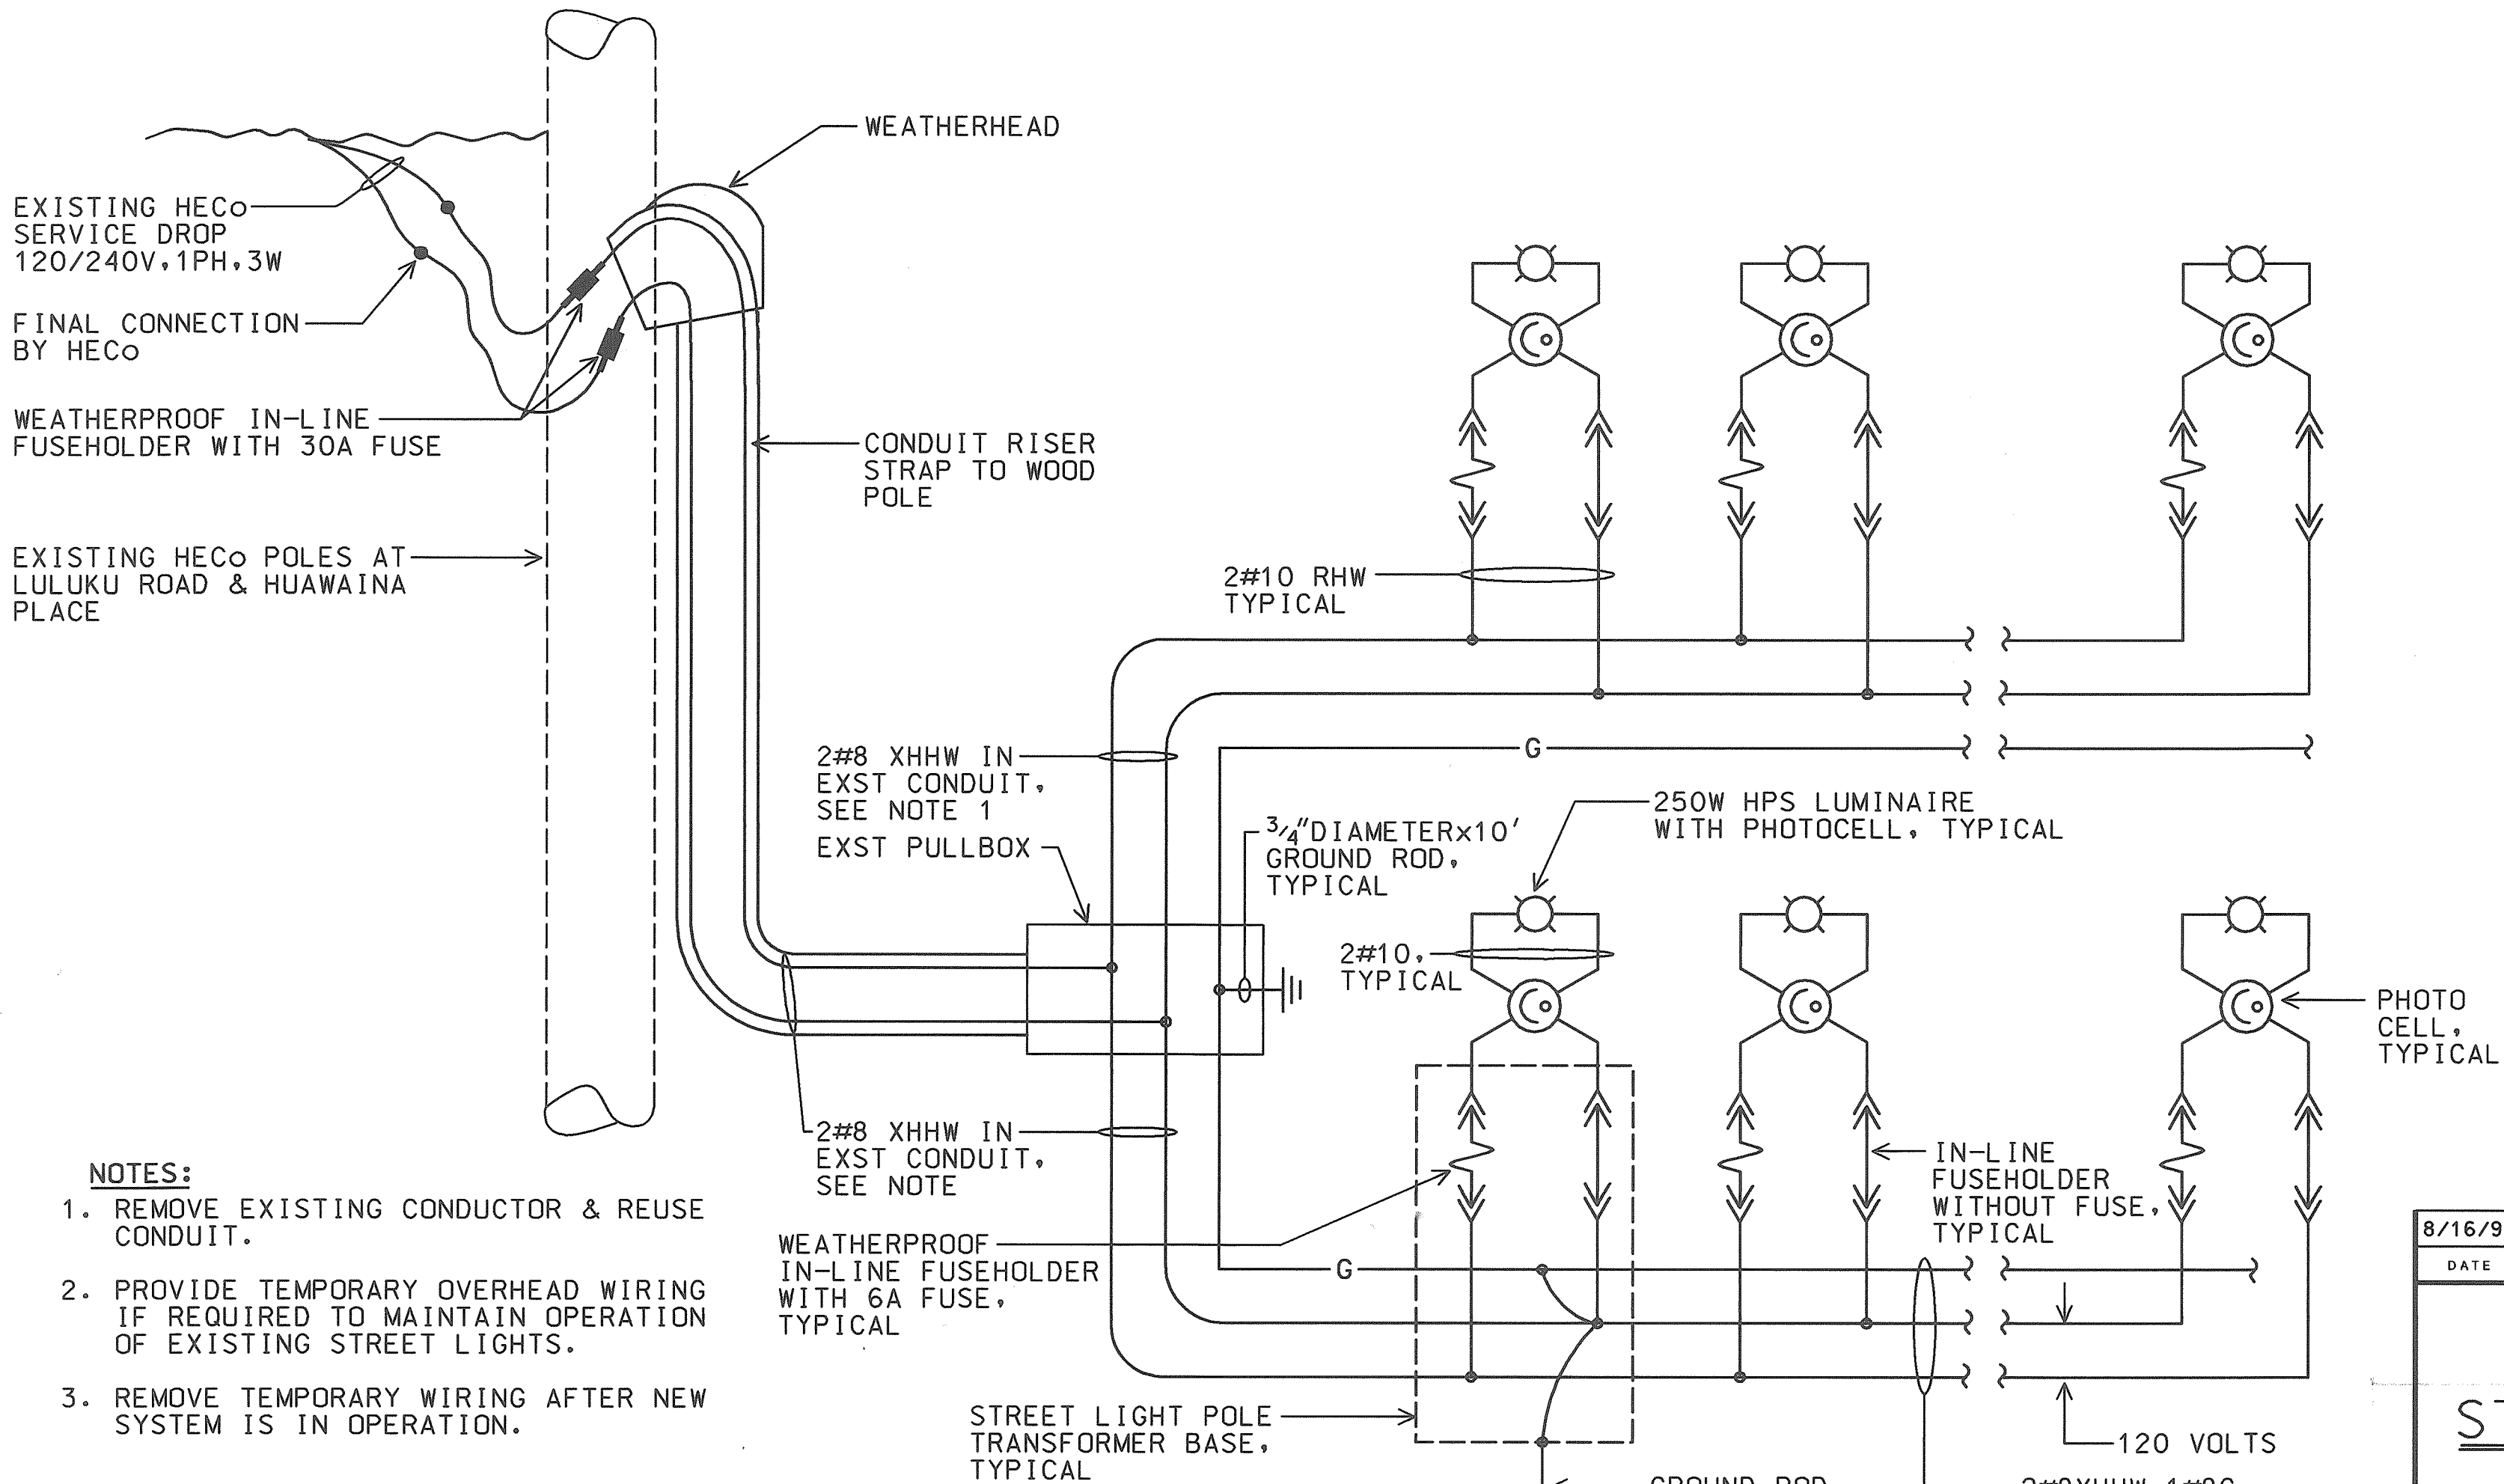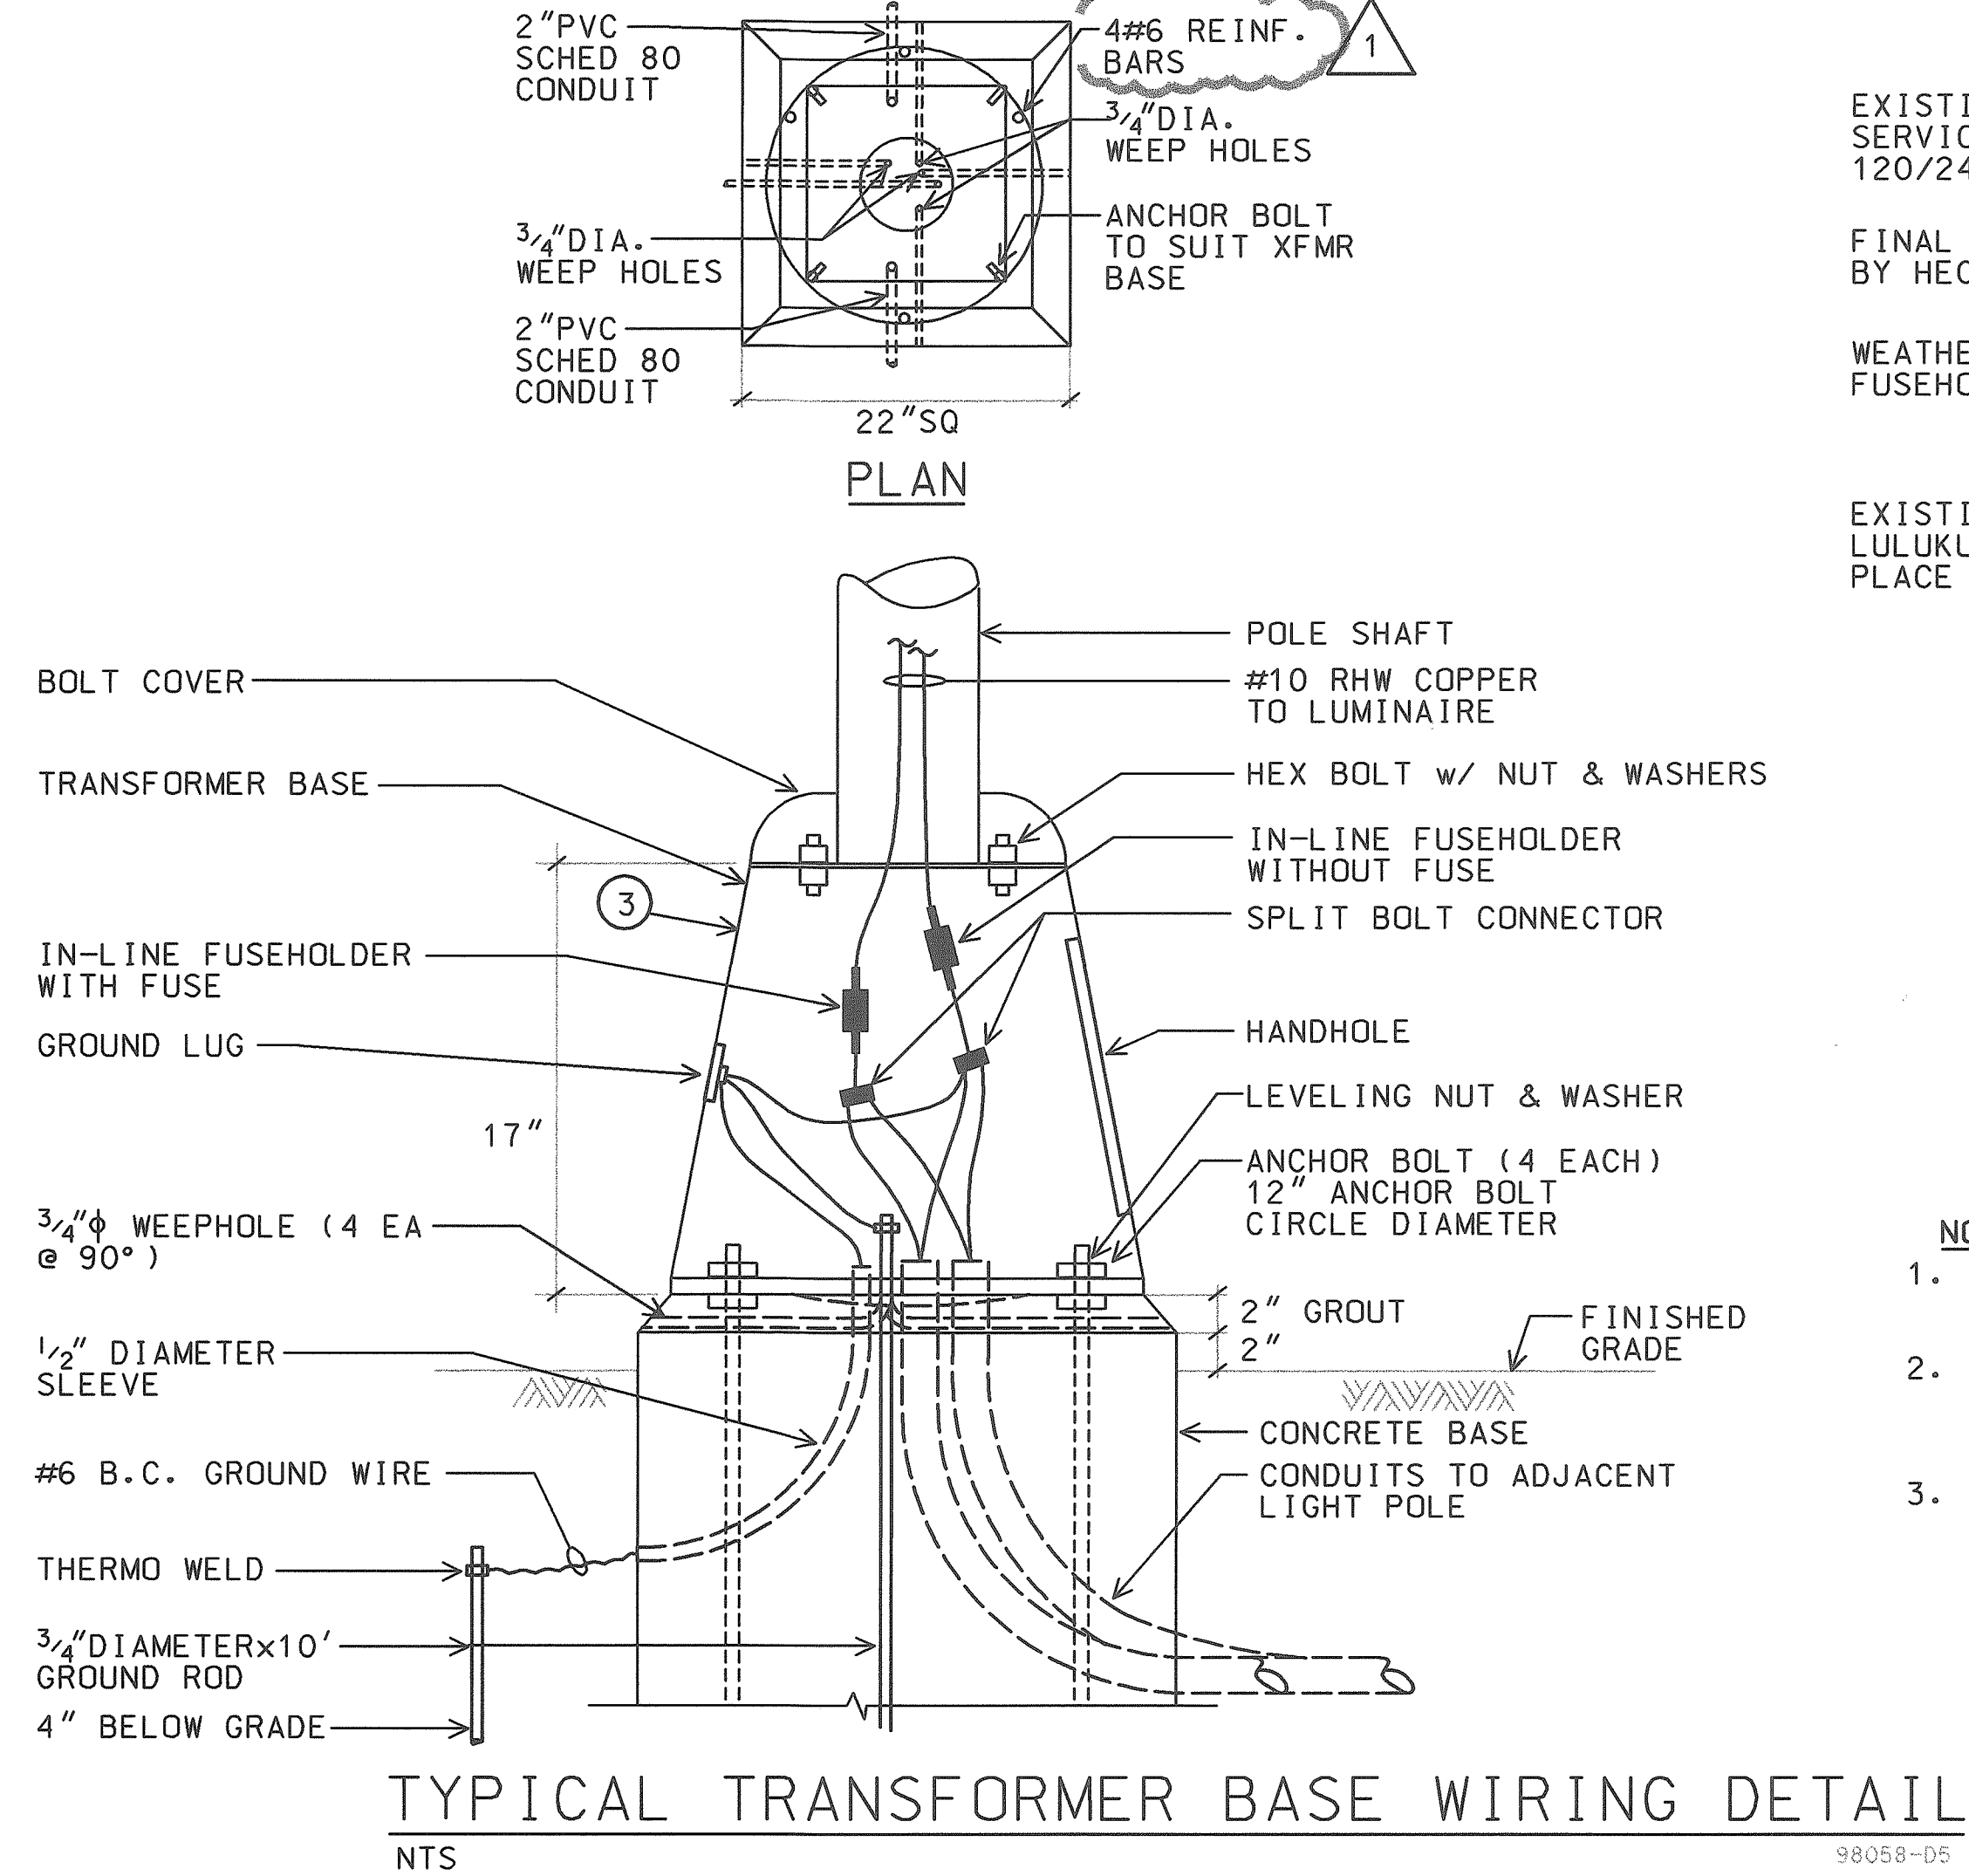


- NOTES:**
- REMOVE EXISTING CONDUCTOR & REUSE CONDUIT.
 - PROVIDE TEMPORARY OVERHEAD WIRING IF REQUIRED TO MAINTAIN OPERATION OF EXISTING STREET LIGHTS.
 - REMOVE TEMPORARY WIRING AFTER NEW SYSTEM IS IN OPERATION.

AS-BUILT

2/4/03

DATE

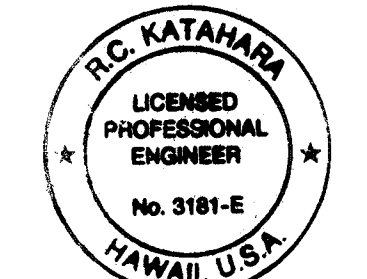



THIS WORK WAS PREPARED BY ME OR UNDER MY SUPERVISION.
MCKelahan 1/25/98
MK ENGINEERS, LTD.

8/16/99		REV. REINF BAR SIZE	DESCRIPTION
DATE	REV		
STATE OF HAWAII DEPARTMENT OF TRANSPORTATION HIGHWAYS DIVISION			
<u>STREET LIGHT DETAIL</u>			
<u>HIGHWAY LIGHTING SAFETY IMPROVEMENTS</u> KAMEHAMEHA HIGHWAY VICINITY OF LIKELIKE HIGHWAY/KANEHOE BAY DRIVE INTERSECTION TO UALANI PLACE			
FEDERAL AID PROJ. NO. STP-0300(66)			
SCALE: AS NOTED		DATE: DECEMBER 1998	
SHEET No. <u>E3</u> OF <u>56</u> SHEETS			

C0-E3

FED. ROAD DIST. NO.	STATE	FED. AID PROJ. NO.	FISCAL YEAR	SHEET NO.	TOTAL SHEETS
HAWAII	HAW.	STP-0300(66)	1998	4	

BEGIN PROJECT
Fed. Aid Proj. No. STP-0300(66)
Sta. 210+10

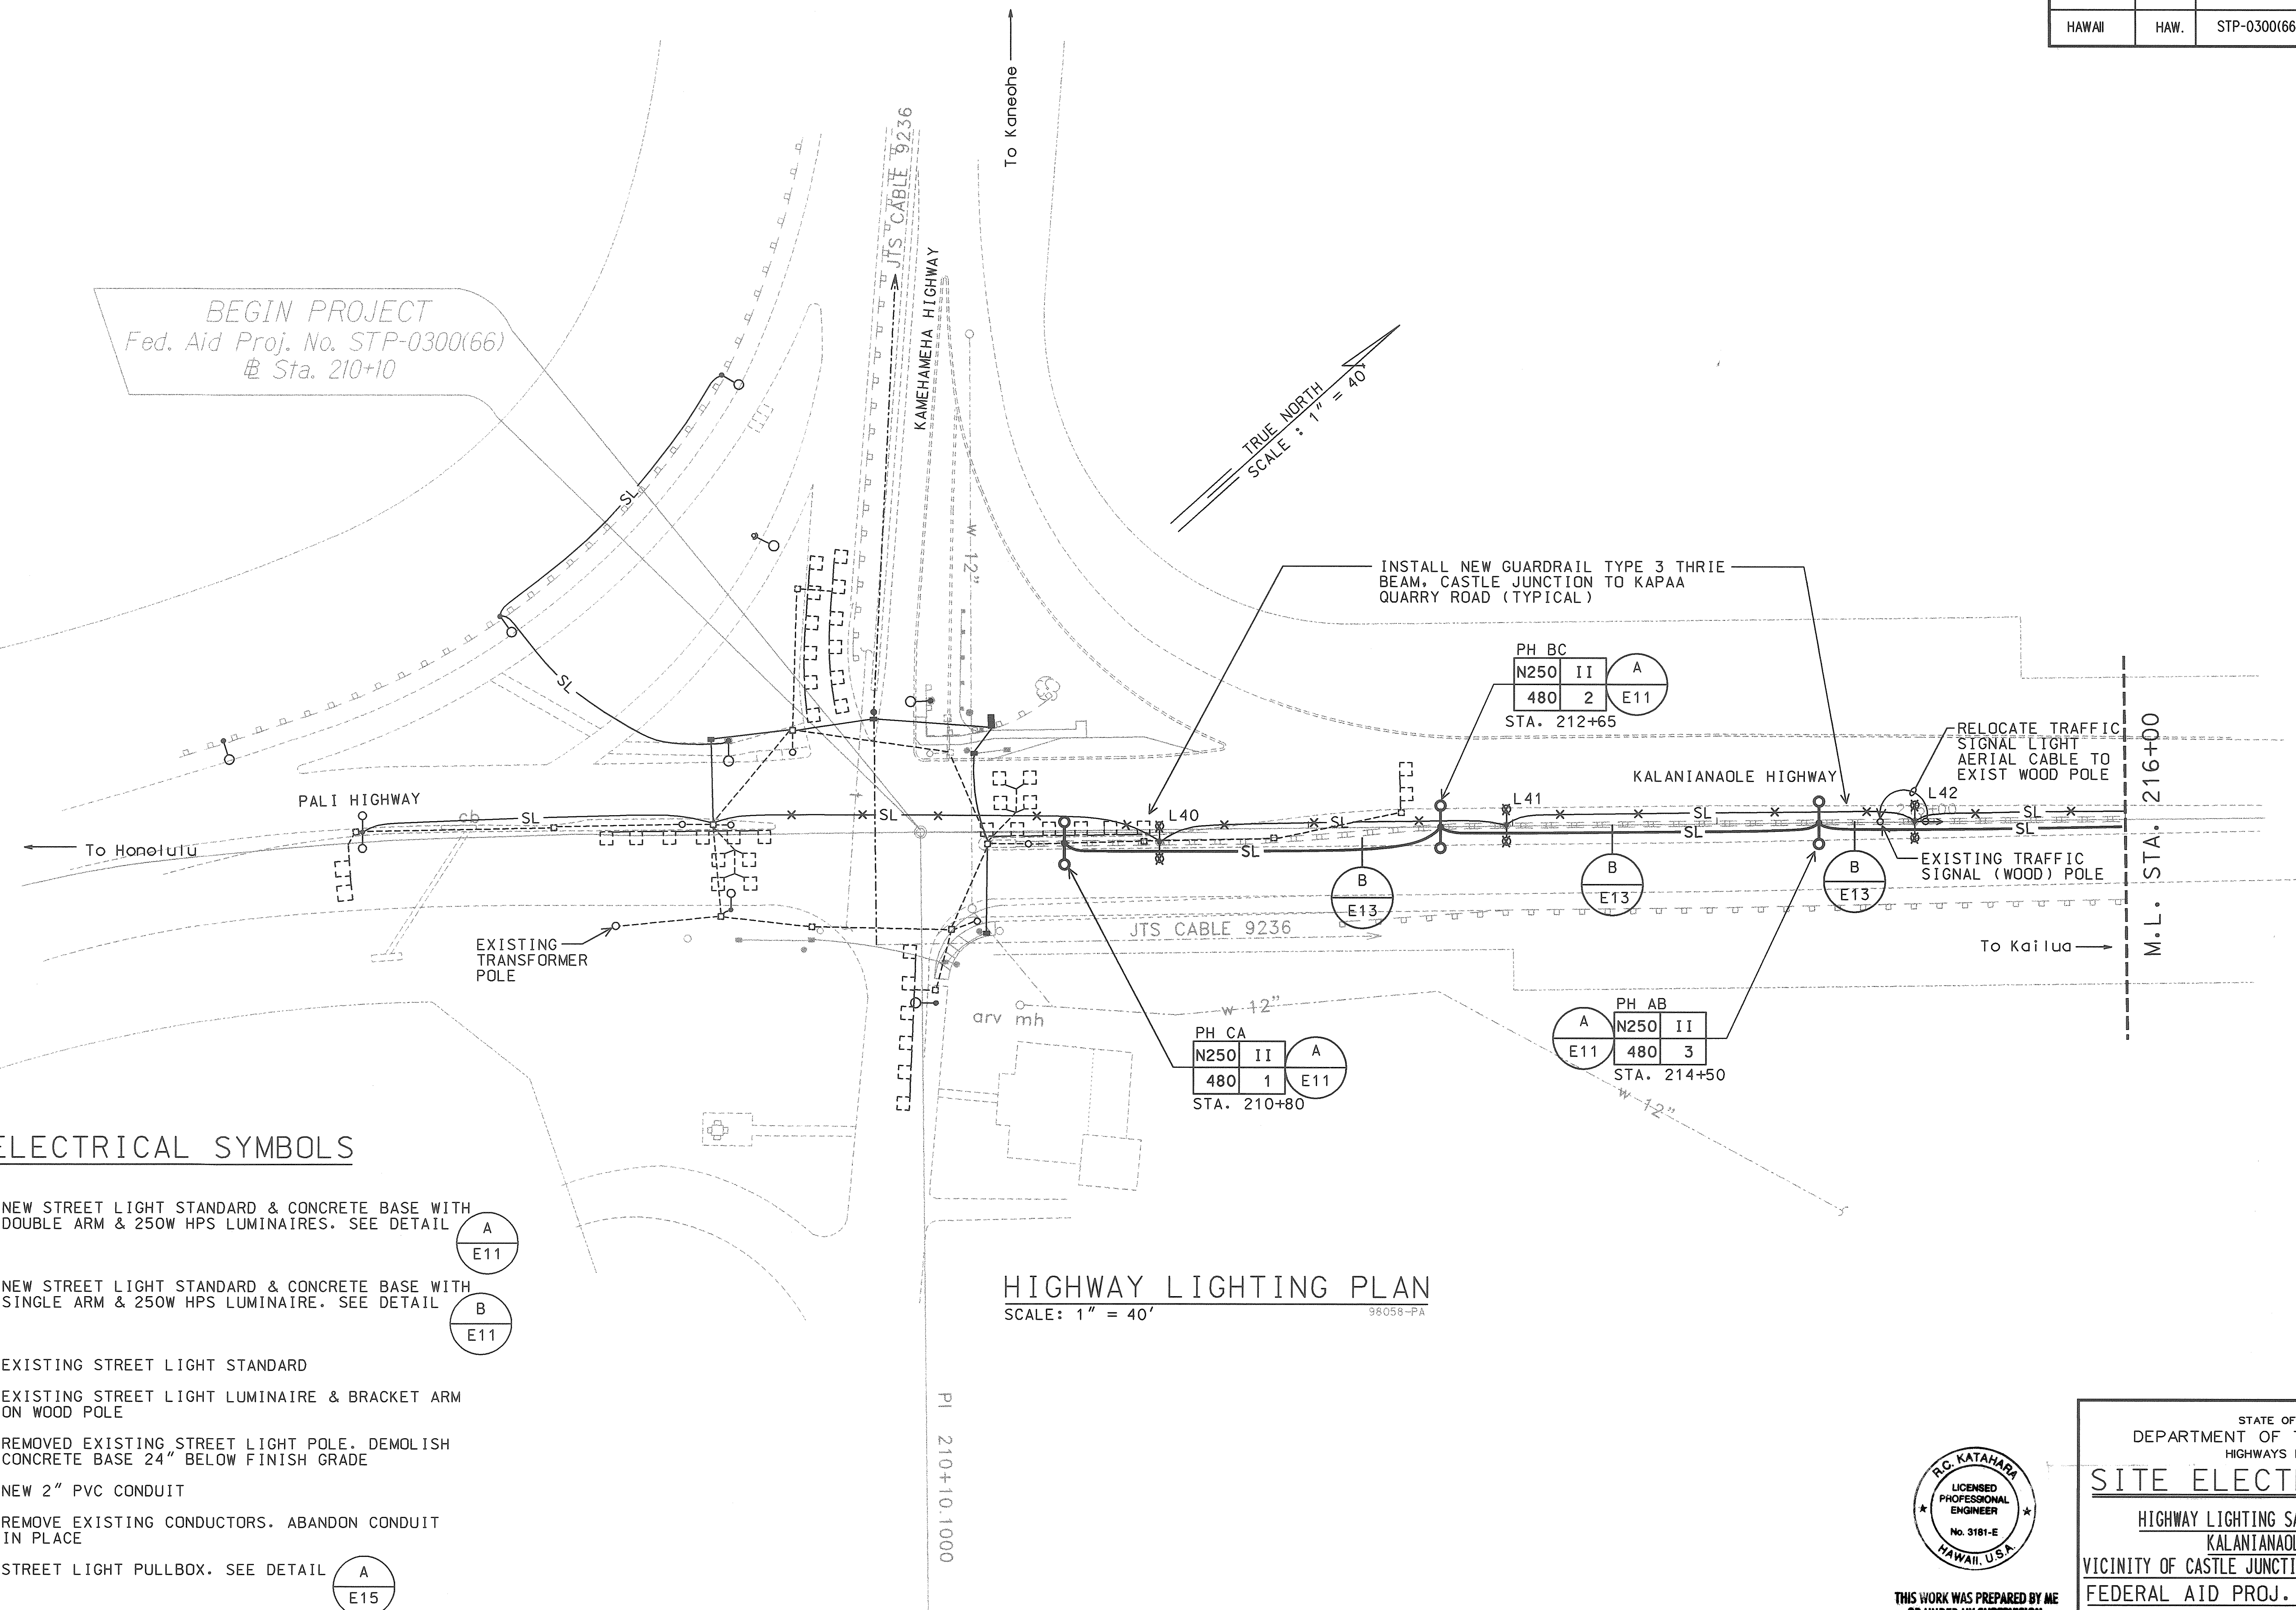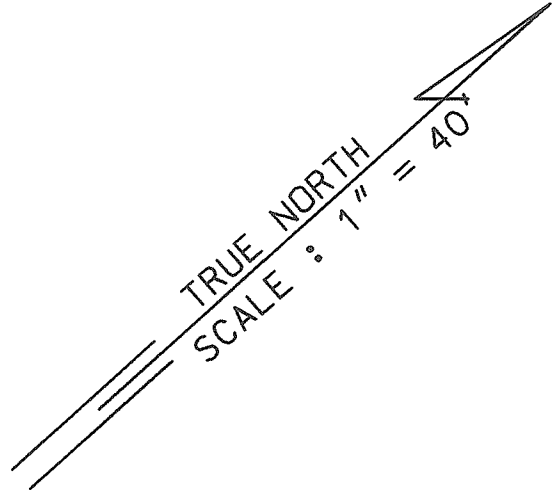


ELECTRICAL SYMBOLS

- NEW STREET LIGHT STANDARD & CONCRETE BASE WITH DOUBLE ARM & 250W HPS LUMINAIRES. SEE DETAIL A
E11
- NEW STREET LIGHT STANDARD & CONCRETE BASE WITH SINGLE ARM & 250W HPS LUMINAIRE. SEE DETAIL B
E11
- EXISTING STREET LIGHT STANDARD
- EXISTING STREET LIGHT LUMINAIRE & BRACKET ARM ON WOOD POLE
- REMOVED EXISTING STREET LIGHT POLE. DEMOLISH CONCRETE BASE 24" BELOW FINISH GRADE
- NEW 2" PVC CONDUIT
- REMOVE EXISTING CONDUCTORS. ABANDON CONDUIT IN PLACE
- STREET LIGHT PULLBOX. SEE DETAIL A
E15

HIGHWAY LIGHTING PLAN
SCALE: 1" = 40'

AS-BUILT
2/4/03
DATE

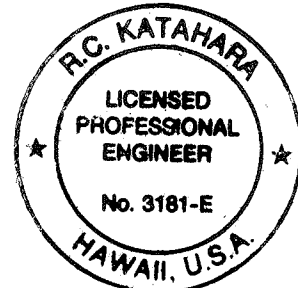

THIS WORK WAS PREPARED BY ME
OR UNDER MY SUPERVISION.
R.C. KATAHARA
MK ENGINEERS, LTD.

STATE OF HAWAII
DEPARTMENT OF TRANSPORTATION
HIGHWAYS DIVISION


SITE ELECTRICAL PLAN

HIGHWAY LIGHTING SAFETY IMPROVEMENTS
KALANIANAʻOLE HIGHWAY
VICINITY OF CASTLE JUNCTION TO WAIMANALO JUNCTION
FEDERAL AID PROJ. NO. STP-0300(66)


SCALE: AS NOTED DATE: DECEMBER 1998

SHEET No. E4 OF 56 SHEETS

FED. ROAD DIST. NO.	STATE	FED. AID PROJ. NO.	FISCAL YEAR	SHEET NO.	TOTAL SHEETS
HAWAII	HAW.	STP-0300(66)	1998	5	

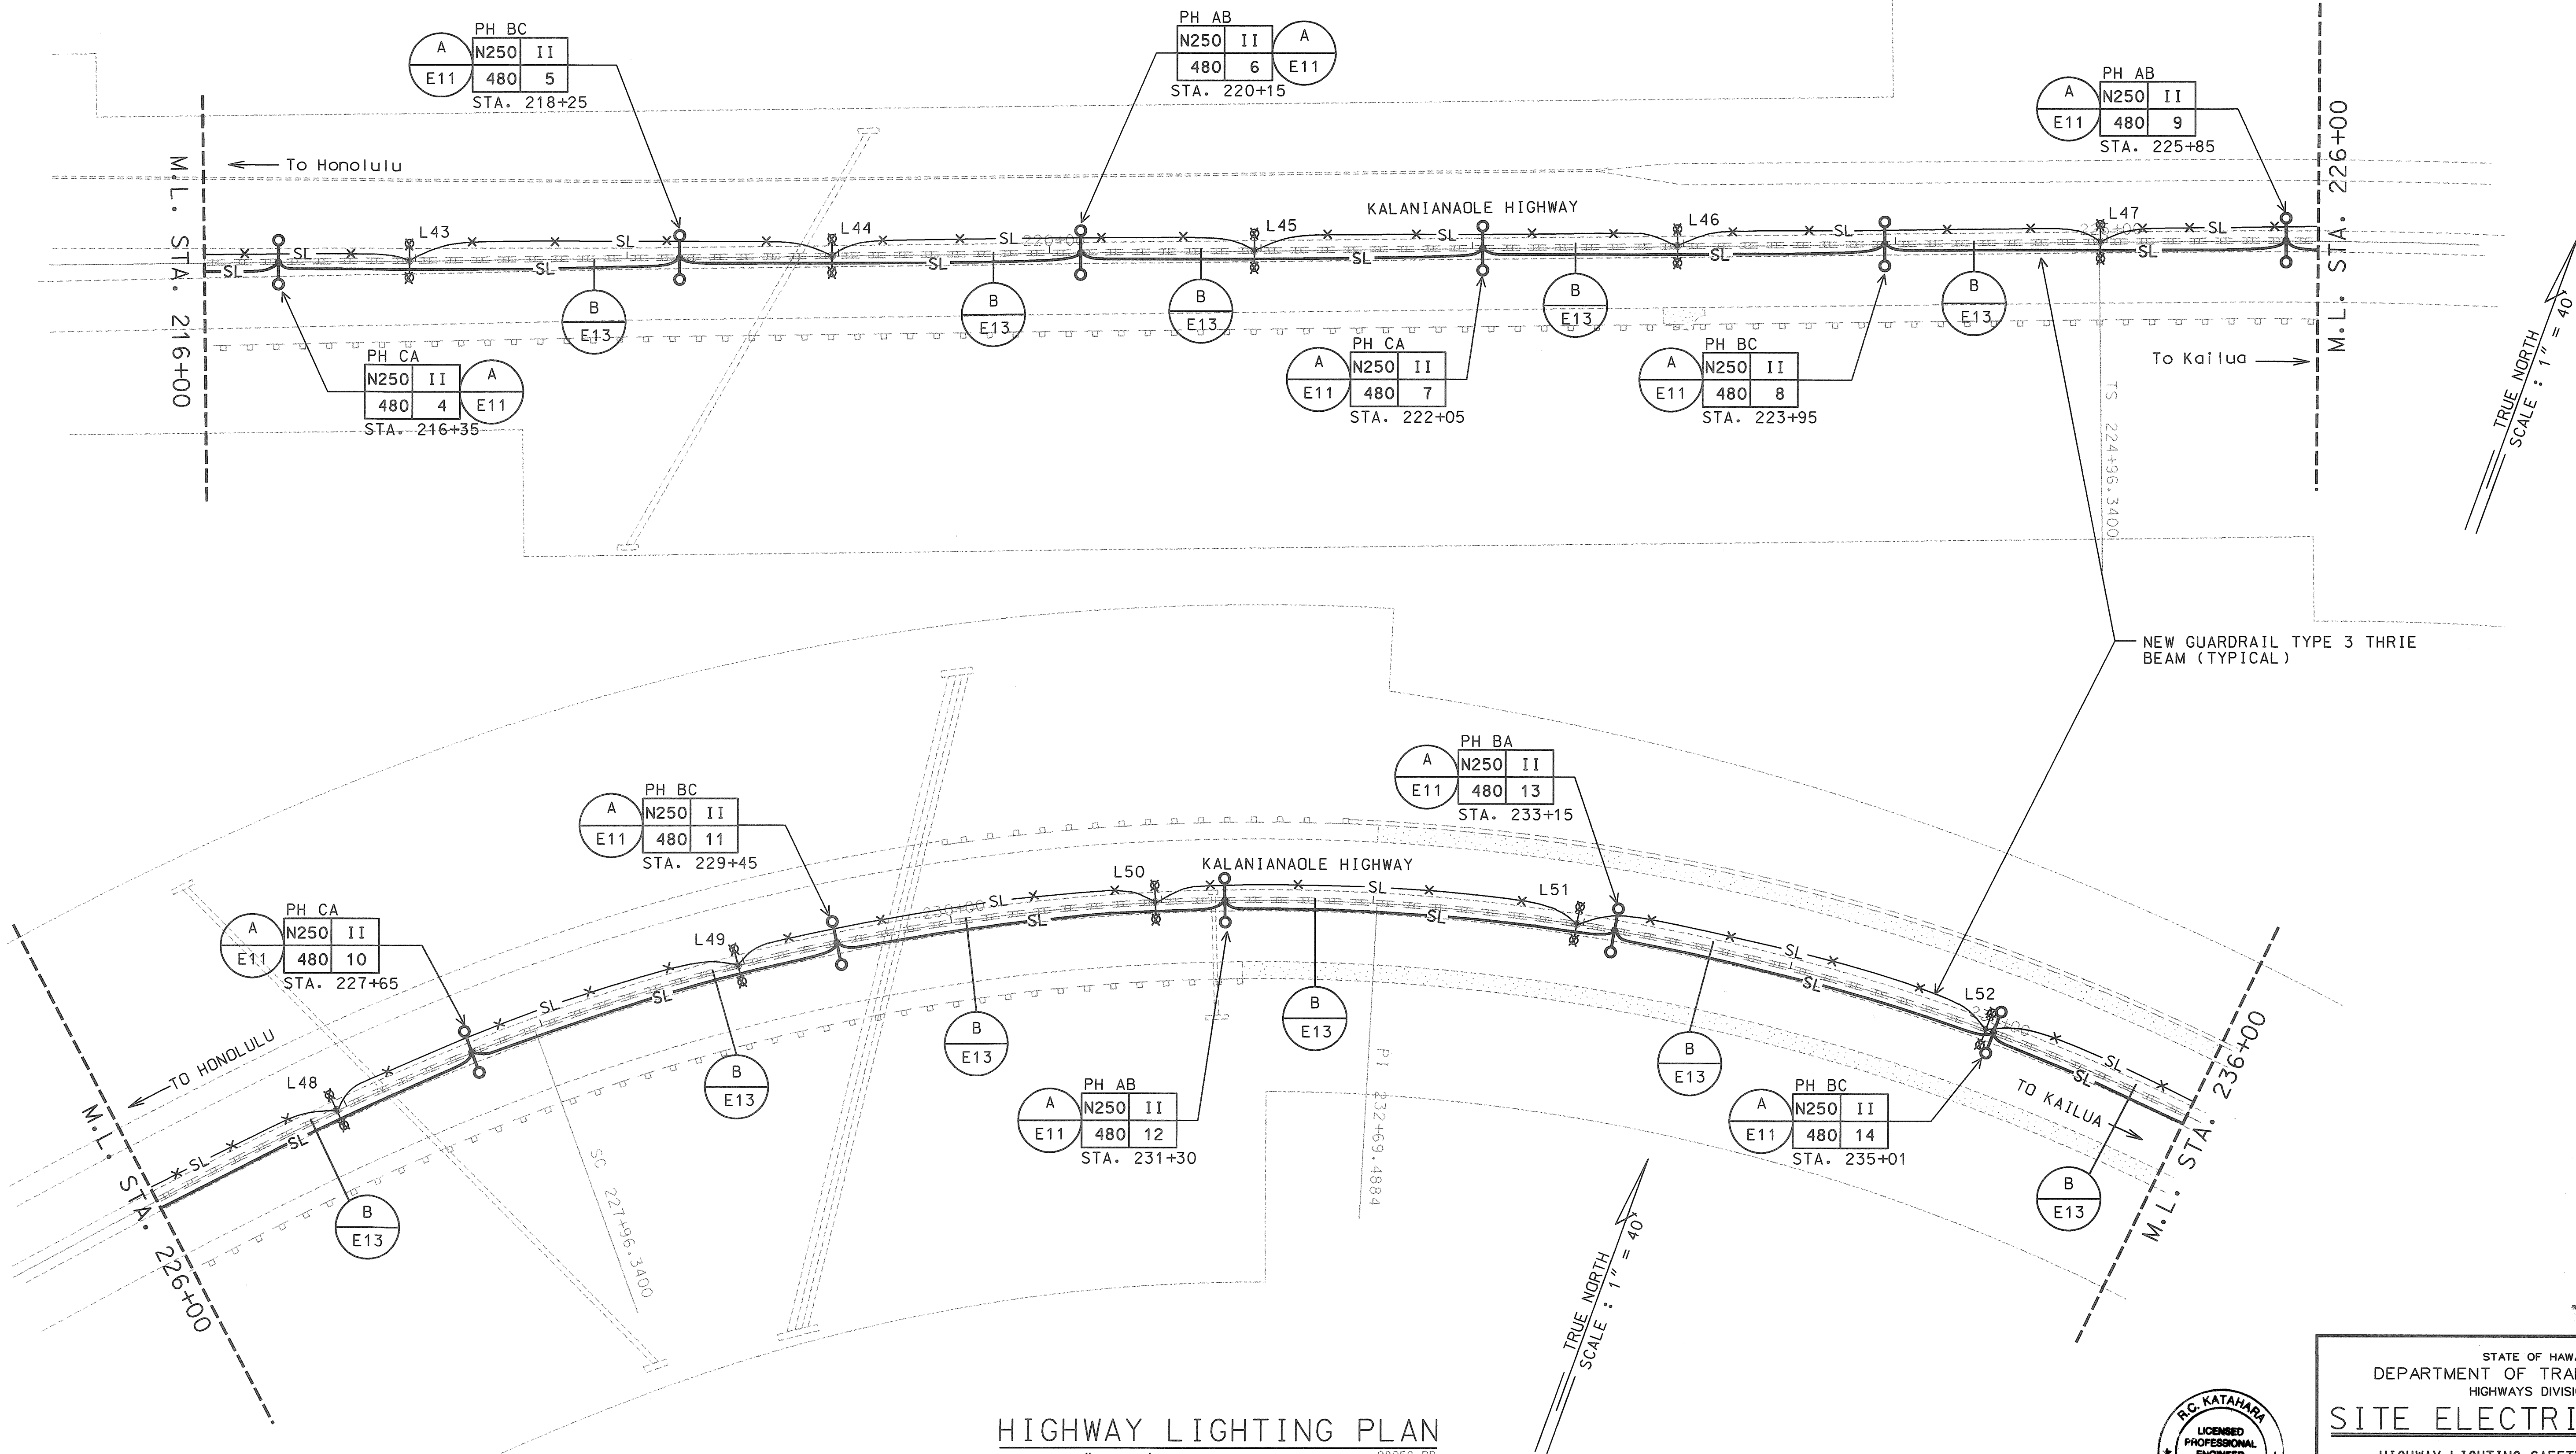

HIGHWAY LIGHTING PLAN
SCALE: 1" = 40'

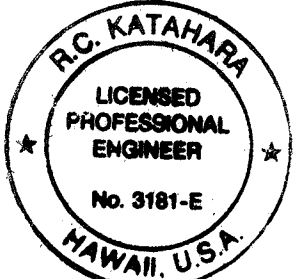

THIS WORK WAS PREPARED BY ME
OR UNDER MY SUPERVISION.
R.C. KATAHARA 11/23/98
MK ENGINEERS, LTD.


STATE OF HAWAII
DEPARTMENT OF TRANSPORTATION
HIGHWAYS DIVISION

SITE ELECTRICAL PLAN


HIGHWAY LIGHTING SAFETY IMPROVEMENTS
KALANIANAʻOLE HIGHWAY
VICINITY OF CASTLE JUNCTION TO WAIMANALO JUNCTION
FEDERAL AID PROJ. NO. STP-0300(66)

SCALE: AS NOTED DATE: DECEMBER 1998
SHEET No. 55 OF 56 SHEETS

FED. ROAD DIST. NO.	STATE	FED. AID PROJ. NO.	FISCAL YEAR	SHEET NO.	TOTAL SHEETS
HAWAII	HAW.	STP-0300(66)	1998	6	

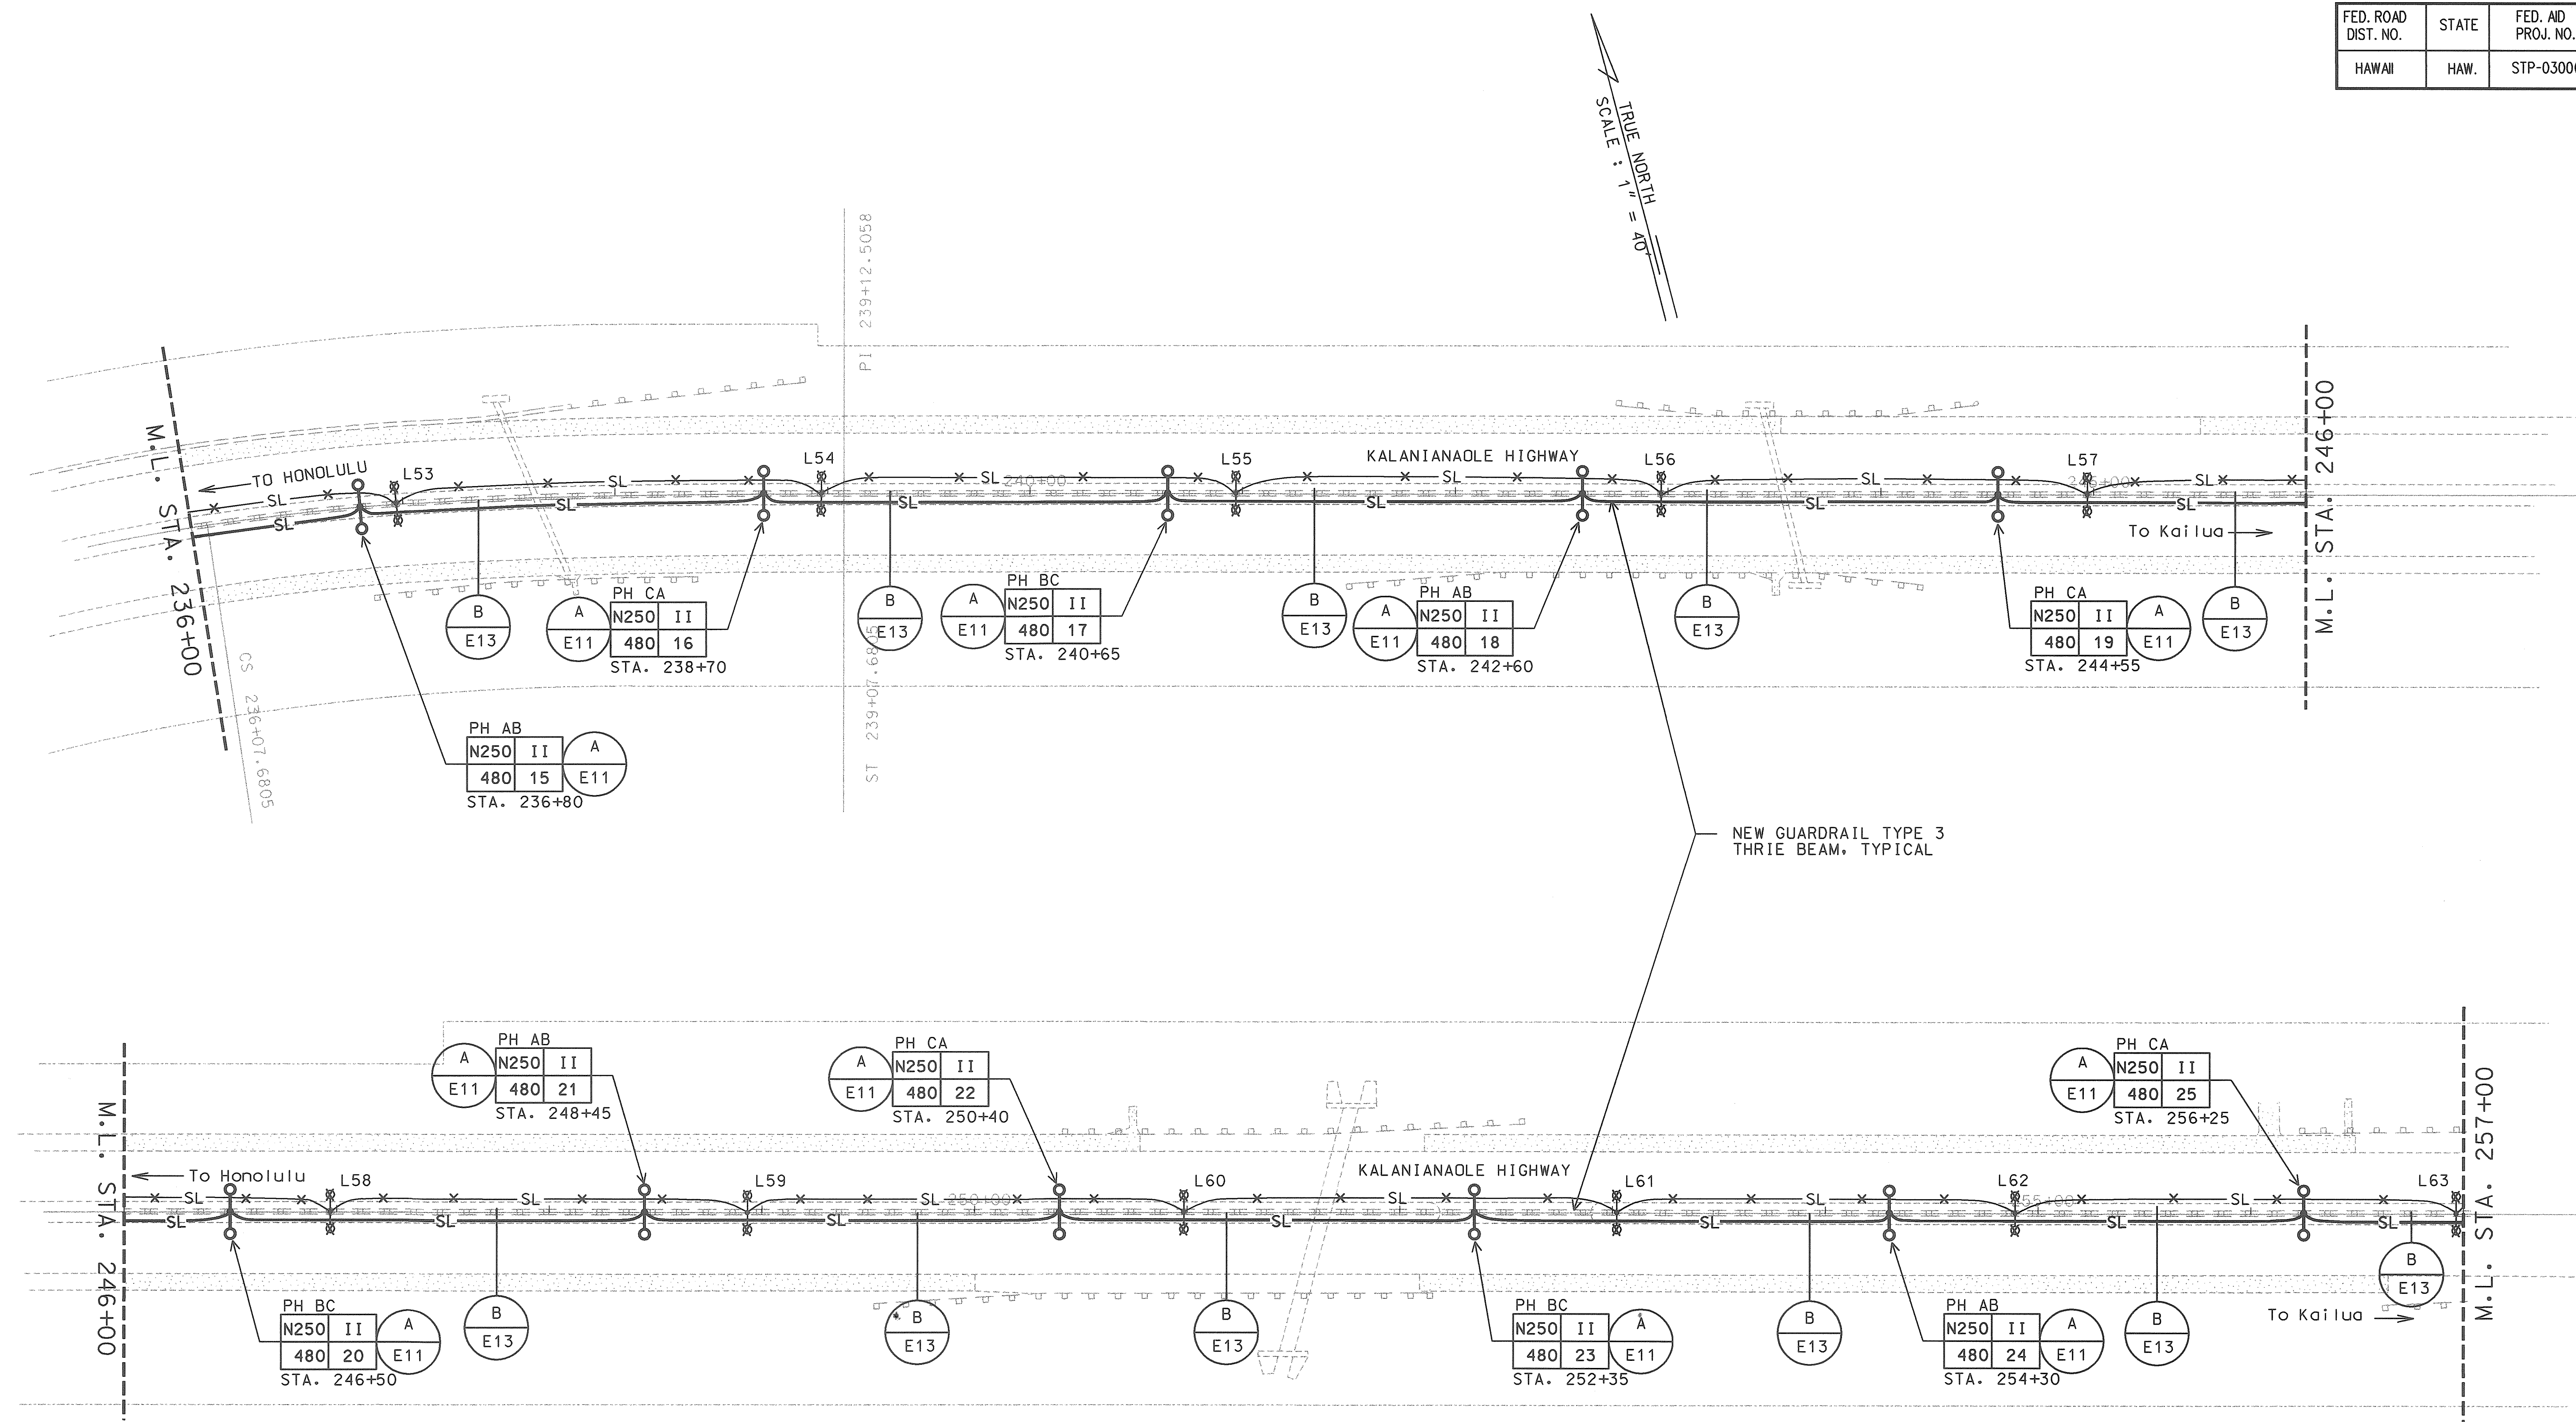

HIGHWAY LIGHTING PLAN
SCALE: 1" = 40'

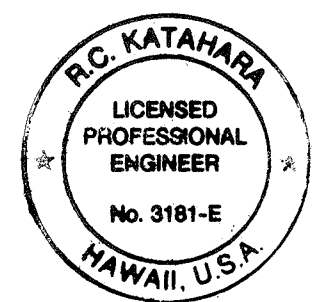

THIS WORK WAS PREPARED BY ME
OR UNDER MY SUPERVISION.
R.C. KATAHARA 1/25/98
MK ENGINEERS, LTD.



STATE OF HAWAII
DEPARTMENT OF TRANSPORTATION
HIGHWAYS DIVISION

SITE ELECTRICAL PLAN


HIGHWAY LIGHTING SAFETY IMPROVEMENTS
KALANIANA'OLE HIGHWAY
VICINITY OF CASTLE JUNCTION TO WAIMANALO JUNCTION
FEDERAL AID PROJ. NO. STP-0300(66)

SCALE: AS NOTED DATE: DECEMBER 1998
SHEET No. E6 OF 56 SHEETS

FED. ROAD DIST. NO.	STATE	FED. AID PROJ. NO.	FISCAL YEAR	SHEET NO.	TOTAL SHEETS
HAWAII	HAW.	STP-0300(66)	1998	7	

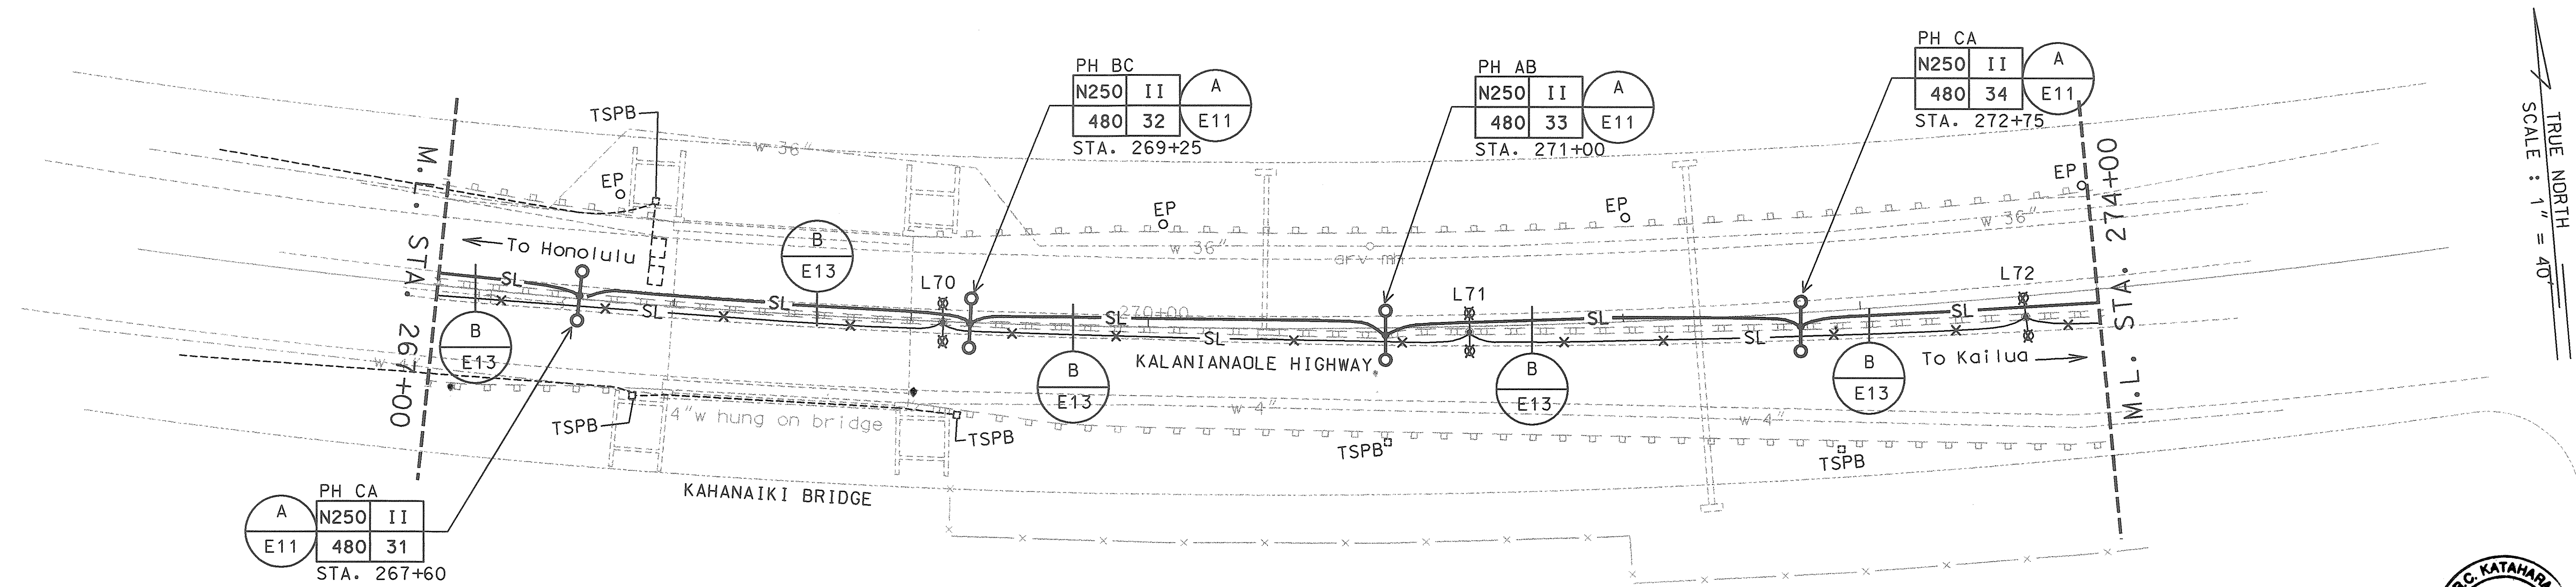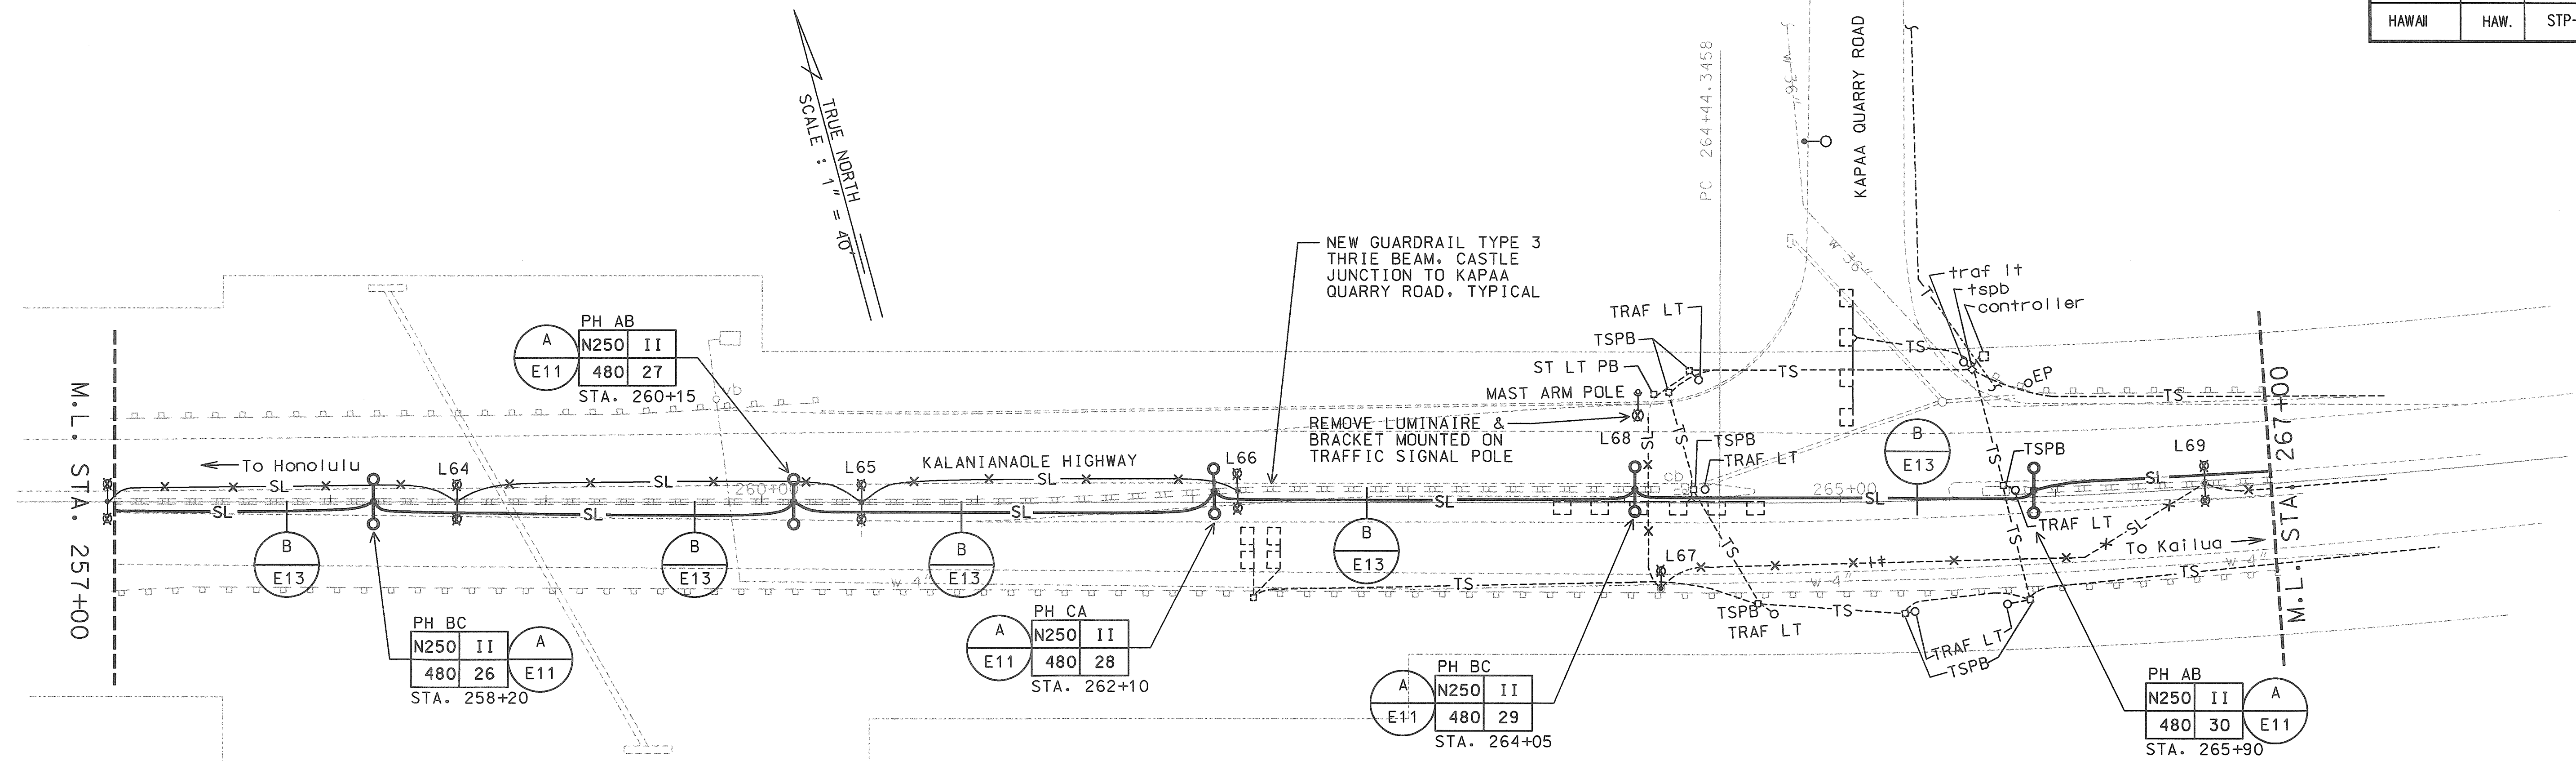

HIGHWAY LIGHTING PLAN
SCALE: 1" = 40'

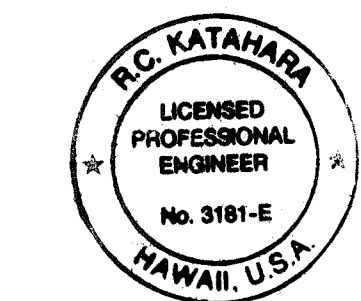


THIS WORK WAS PREPARED BY
OR UNDER MY SUPERVISION.
R.C. KATAHARA
MK ENGINEERS, LTD.

AS-BUILT
DATE: 12/9/98

STATE OF HAWAII DEPARTMENT OF TRANSPORTATION HIGHWAYS DIVISION
SITE ELECTRICAL PLAN
HIGHWAY LIGHTING SAFETY IMPROVEMENTS KALANIANA'OLE HIGHWAY VICINITY OF CASTLE JUNCTION TO WAIMANALO JUNCTION FEDERAL AID PROJ. NO. STP-0300(66)
SCALE: AS NOTED DATE: DECEMBER 1998 SHEET No. 67 OF 66 SHEETS

FED. ROAD DIST. NO.	STATE	FED. AID PROJ. NO.	FISCAL YEAR	SHEET NO.	TOTAL SHEETS
HAWAII	HAW.	STP-0300(66)	1998	8	

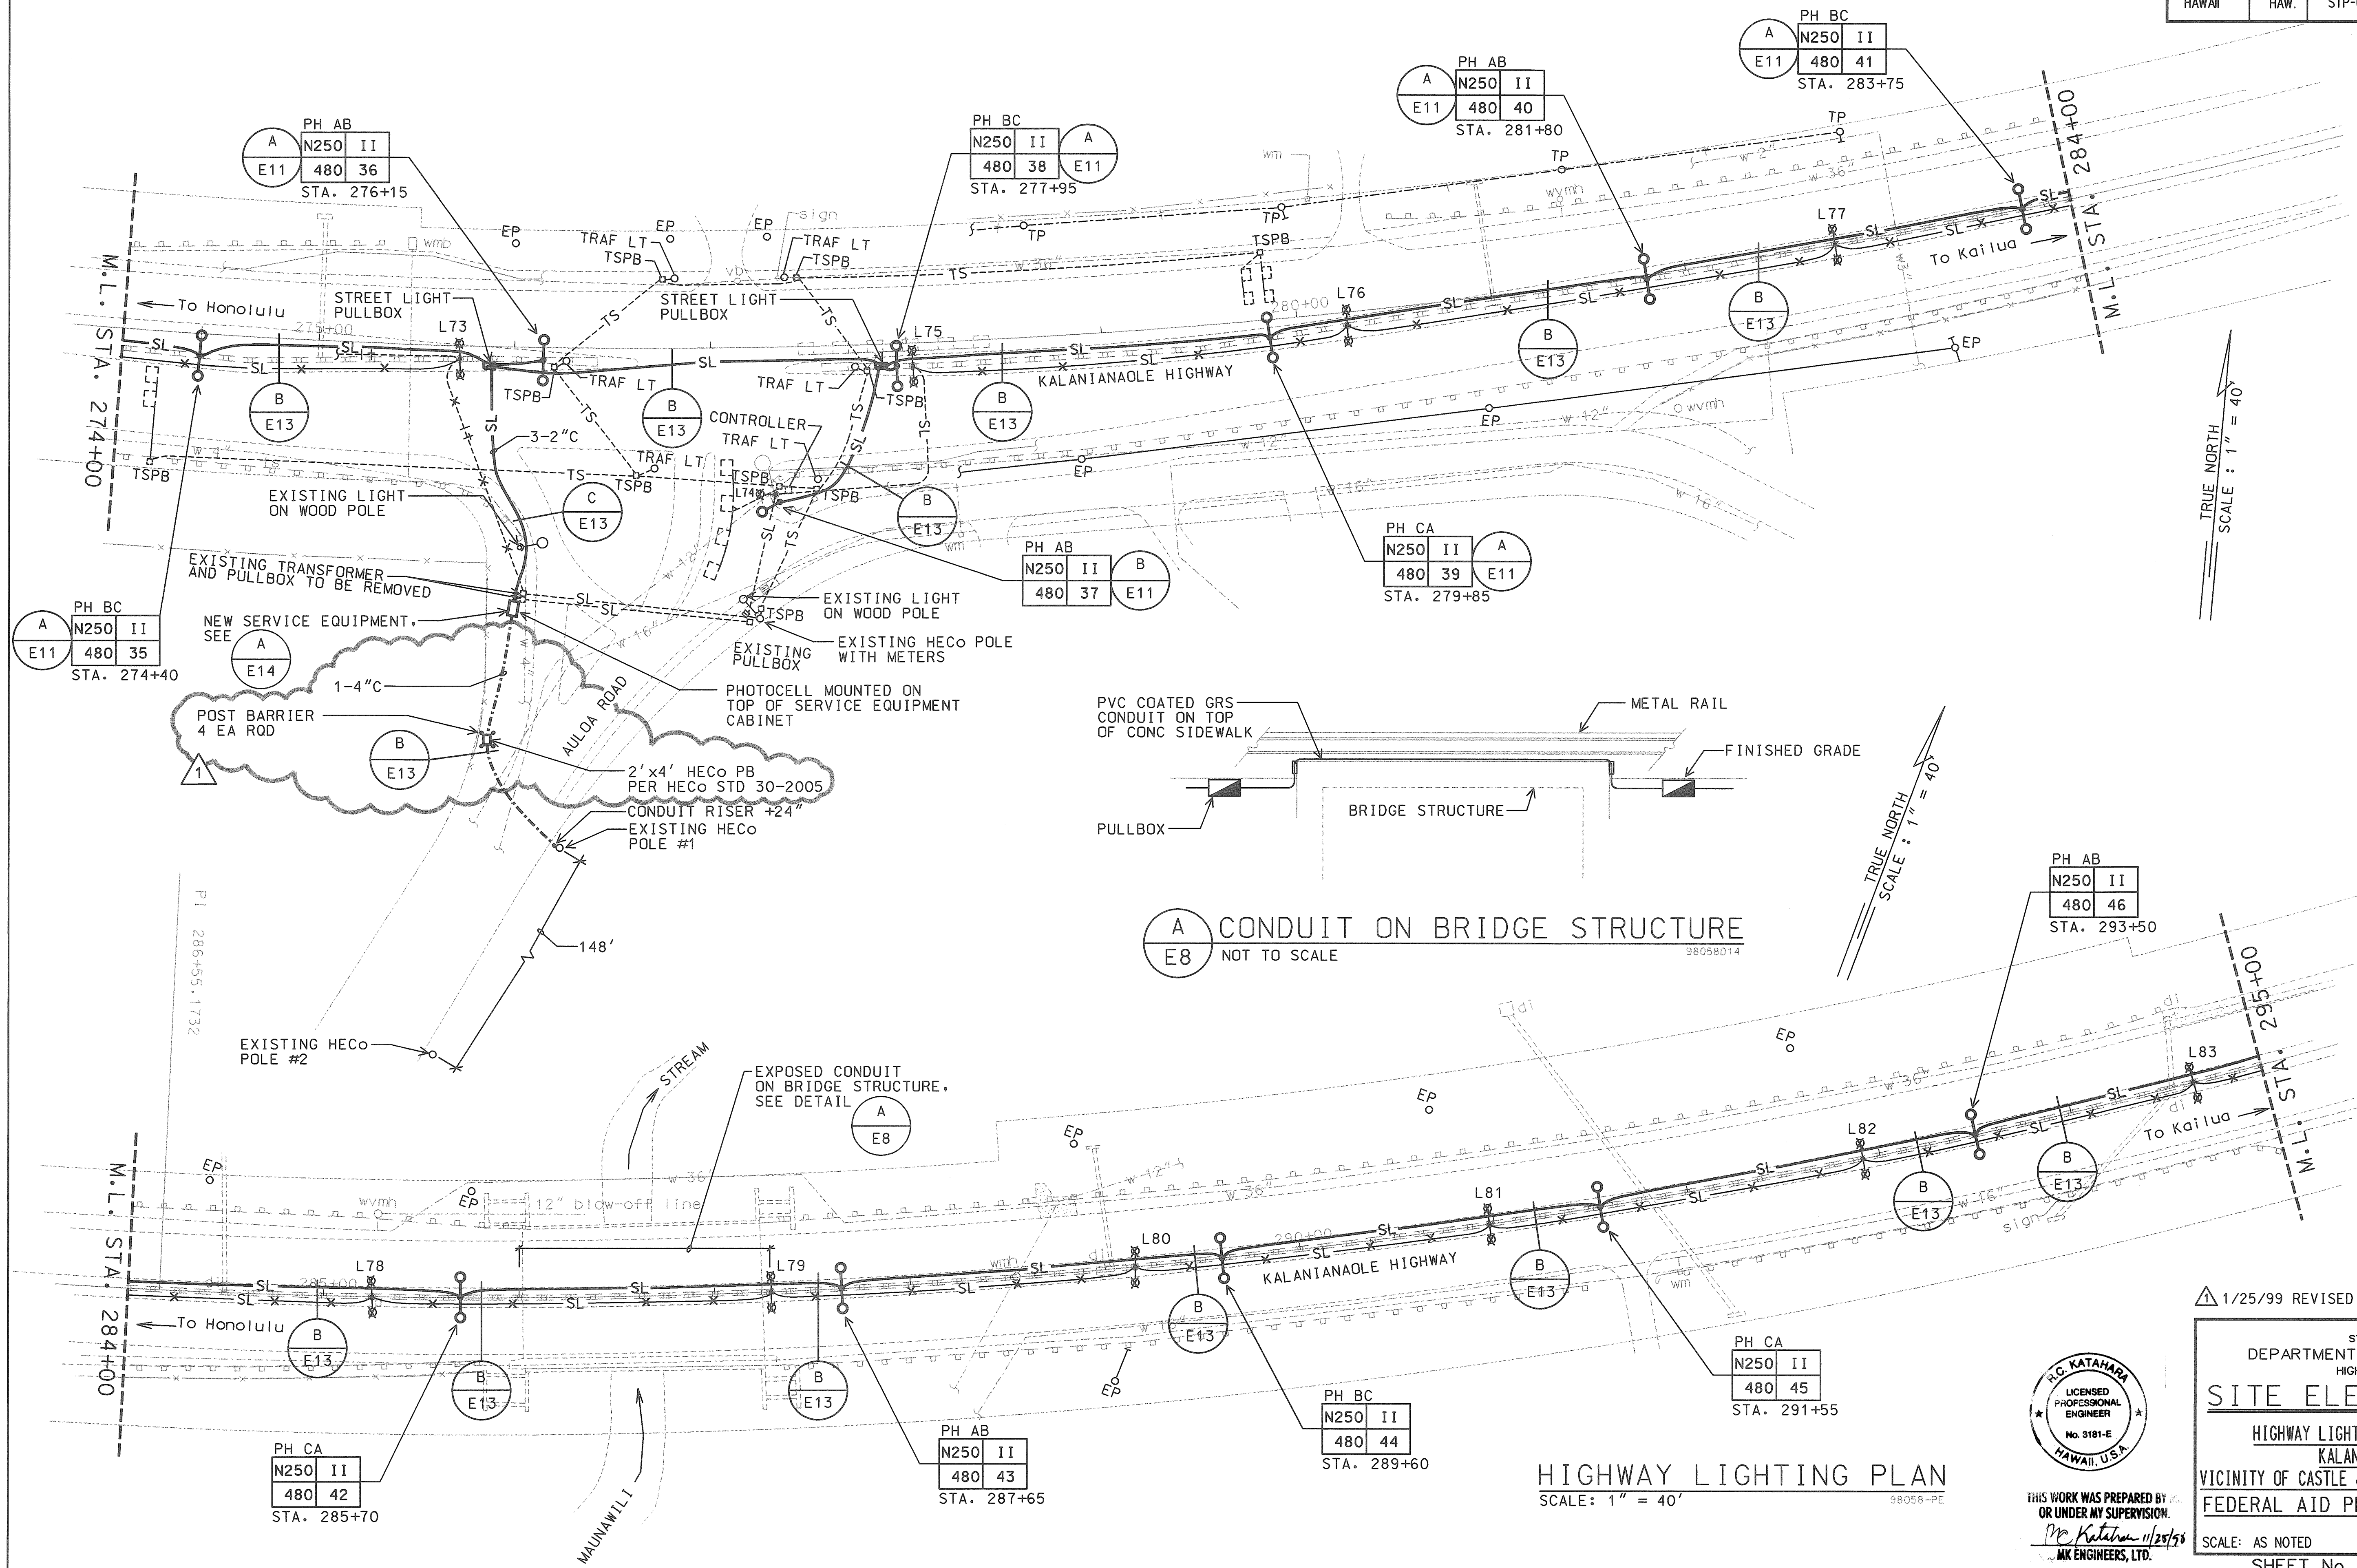


TRUE NORTH
SCALE : 1" = 40'

TRUE NORTH
SCALE : 1" = 40'

AS-BUILT
2/8/03

1/25/99 REVISED TO COMPLY WITH HECO SVC DWGS

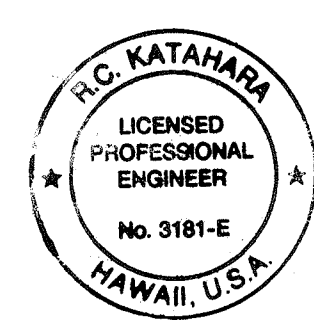

THIS WORK WAS PREPARED BY
OR UNDER MY SUPERVISION.
Mr. Katchan 1/25/98
MK ENGINEERS, LTD.

STATE OF HAWAII
DEPARTMENT OF TRANSPORTATION
HIGHWAYS DIVISION


SITE ELECTRICAL PLAN
HIGHWAY LIGHTING SAFETY IMPROVEMENTS
KALANIANAʻOLE HIGHWAY
VICINITY OF CASTLE JUNCTION TO WAIMANALO JUNCTION
FEDERAL AID PROJ. NO. STP-0300(66)

SCALE: AS NOTED DATE: DECEMBER 1998

SHEET No. **E8** OF **56** SHEETS


HIGHWAY LIGHTING PLAN
SCALE: 1" = 40'

FED. ROAD DIST. NO.	STATE	FED. AID PROJ. NO.	FISCAL YEAR	SHEET NO.	TOTAL SHEETS
HAWAII	HAW.	STP-0300(66)	1998	9	

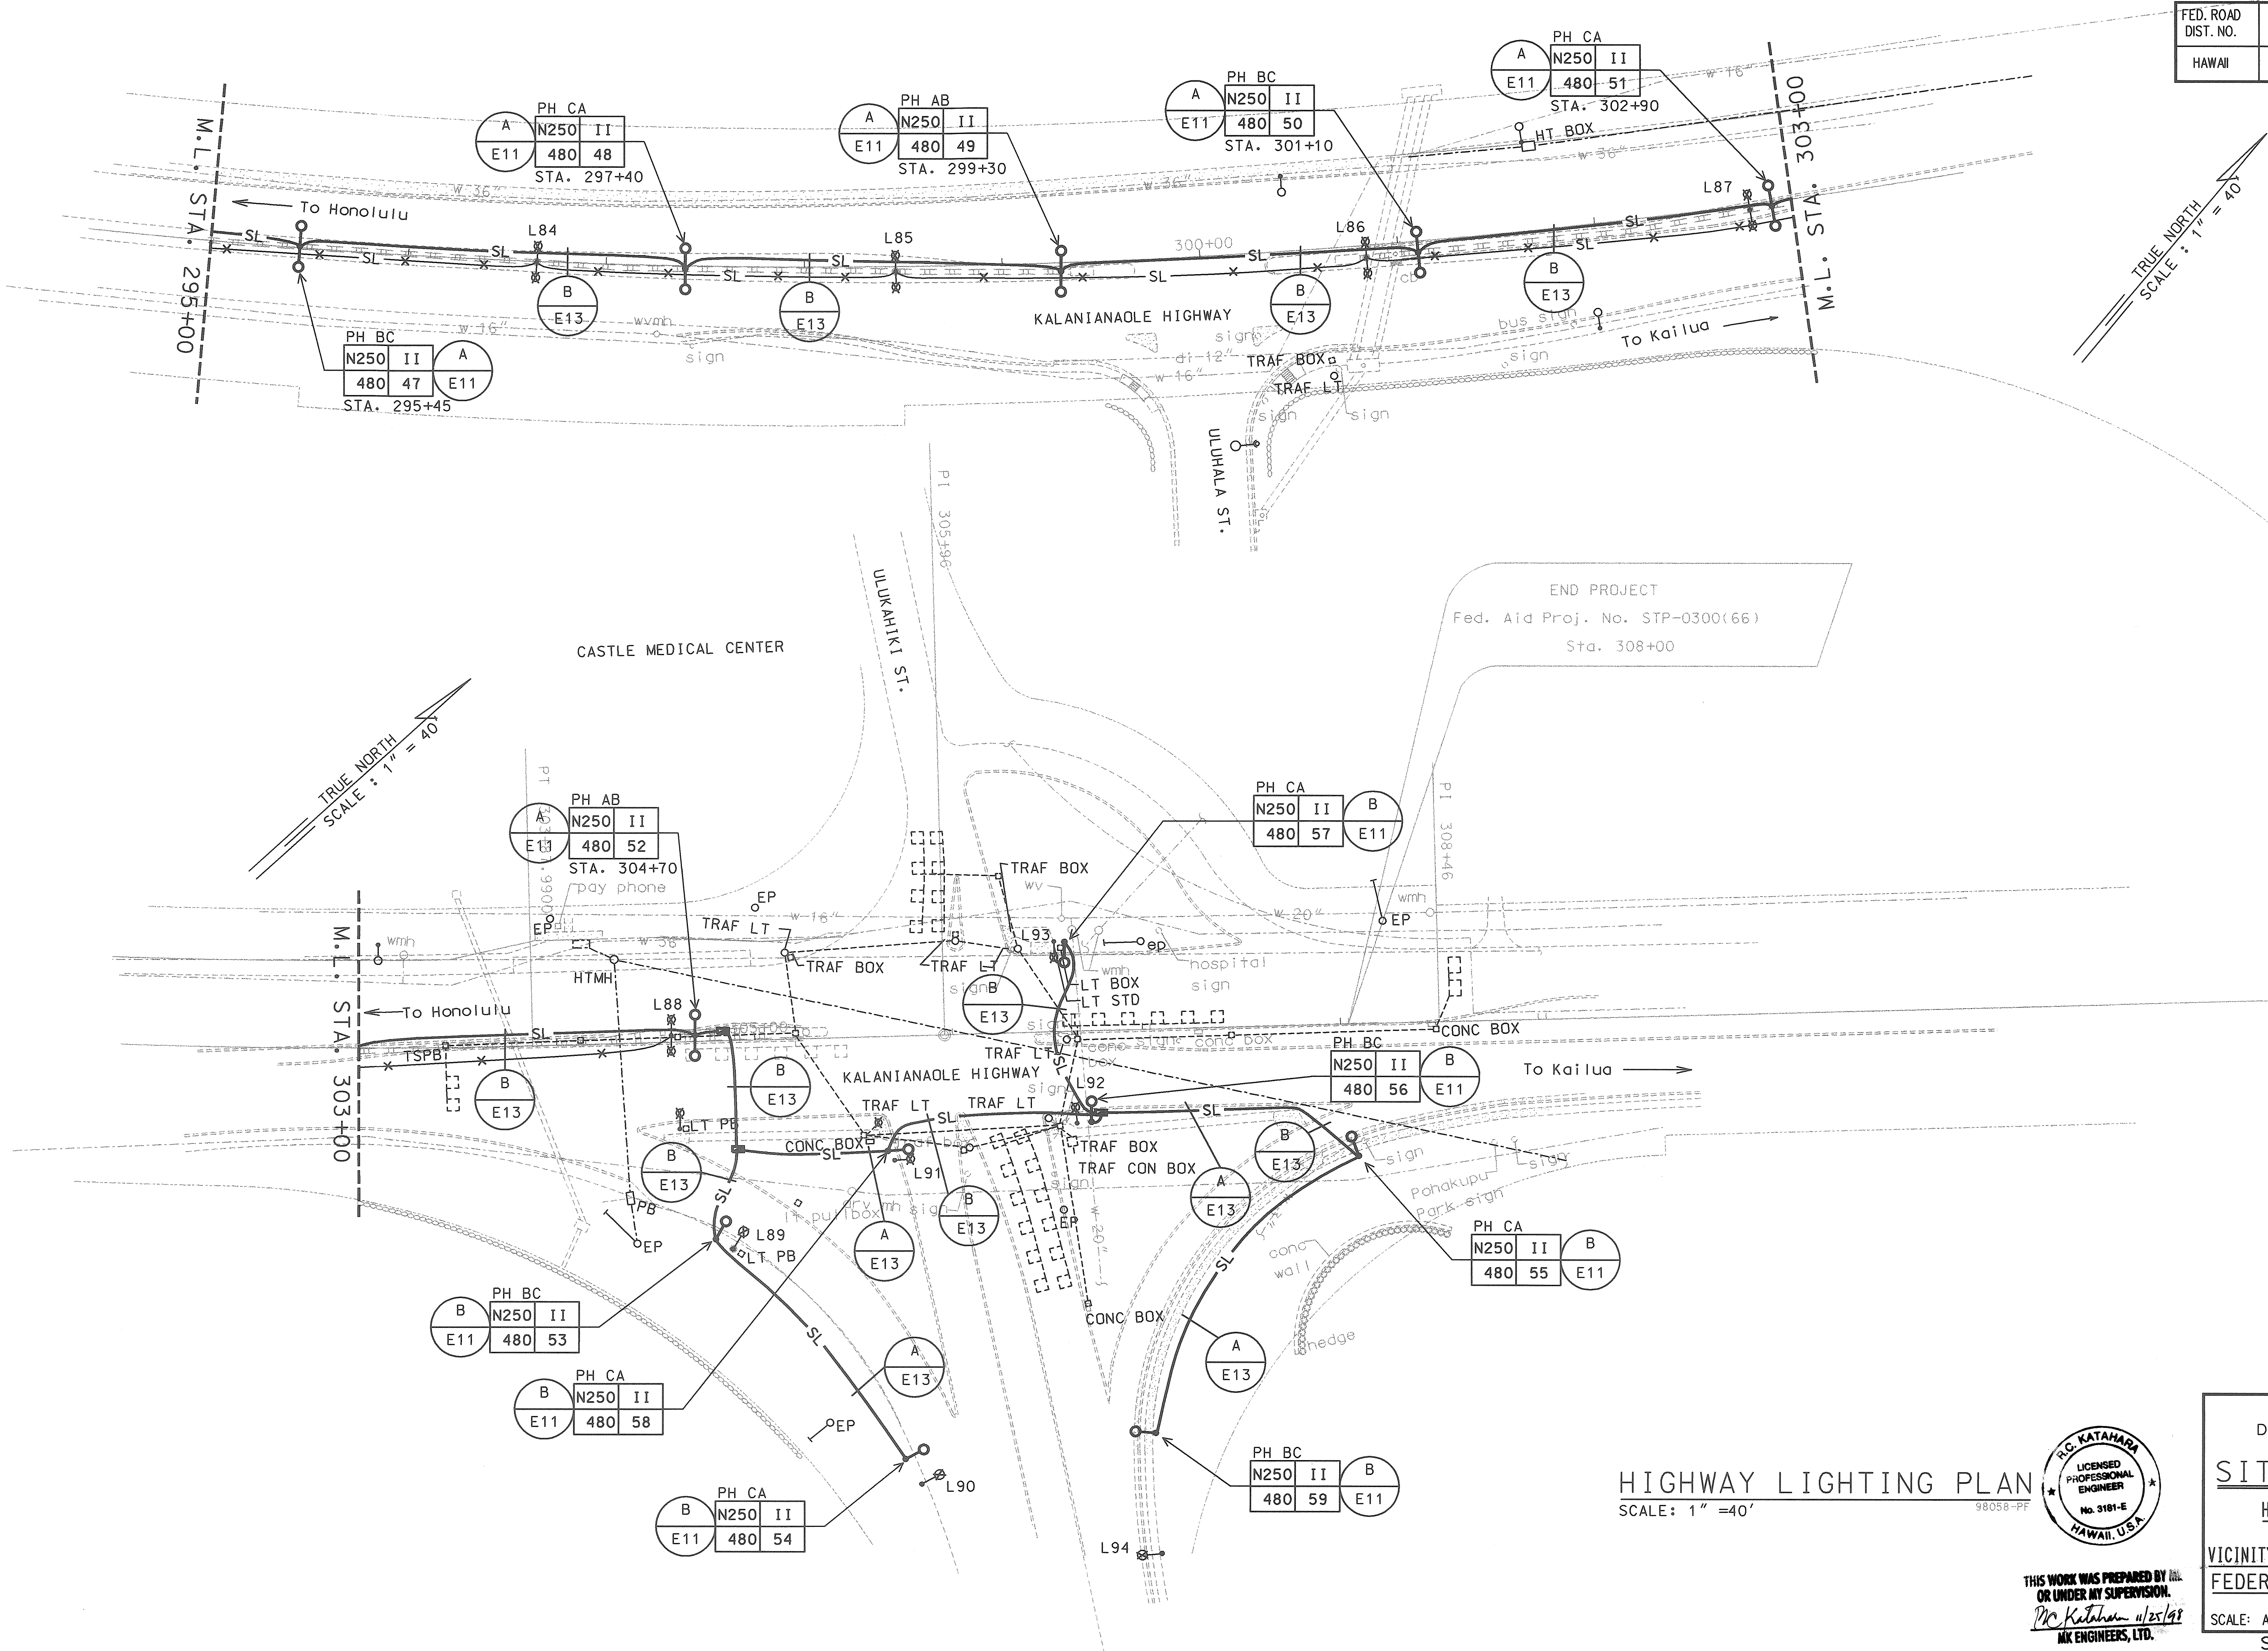

AS-BUILT
2/4/03
DATE

HIGHWAY LIGHTING PLAN
SCALE: 1" = 40'

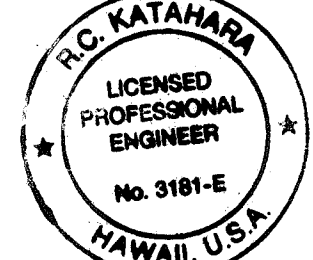

THIS WORK WAS PREPARED BY ME
OR UNDER MY SUPERVISION.
R.C. KATAHARA 11/25/98
MK ENGINEERS, LTD.


STATE OF HAWAII
DEPARTMENT OF TRANSPORTATION
HIGHWAYS DIVISION

SITE ELECTRICAL PLAN

HIGHWAY LIGHTING SAFETY IMPROVEMENTS
KALANIANAʻOLE HIGHWAY
VICINITY OF CASTLE JUNCTION TO WAIMANALO JUNCTION
FEDERAL AID PROJ. NO. STP-0300(66)


SCALE: AS NOTED DATE: DECEMBER 1998
SHEET No. **9** OF **56** SHEETS

FED. ROAD DIST. NO.	STATE	FED. AID PROJ. NO.	FISCAL YEAR	SHEET NO.	TOTAL SHEETS
HAWAII	HAW.	STP-0300(66)	1998	10	

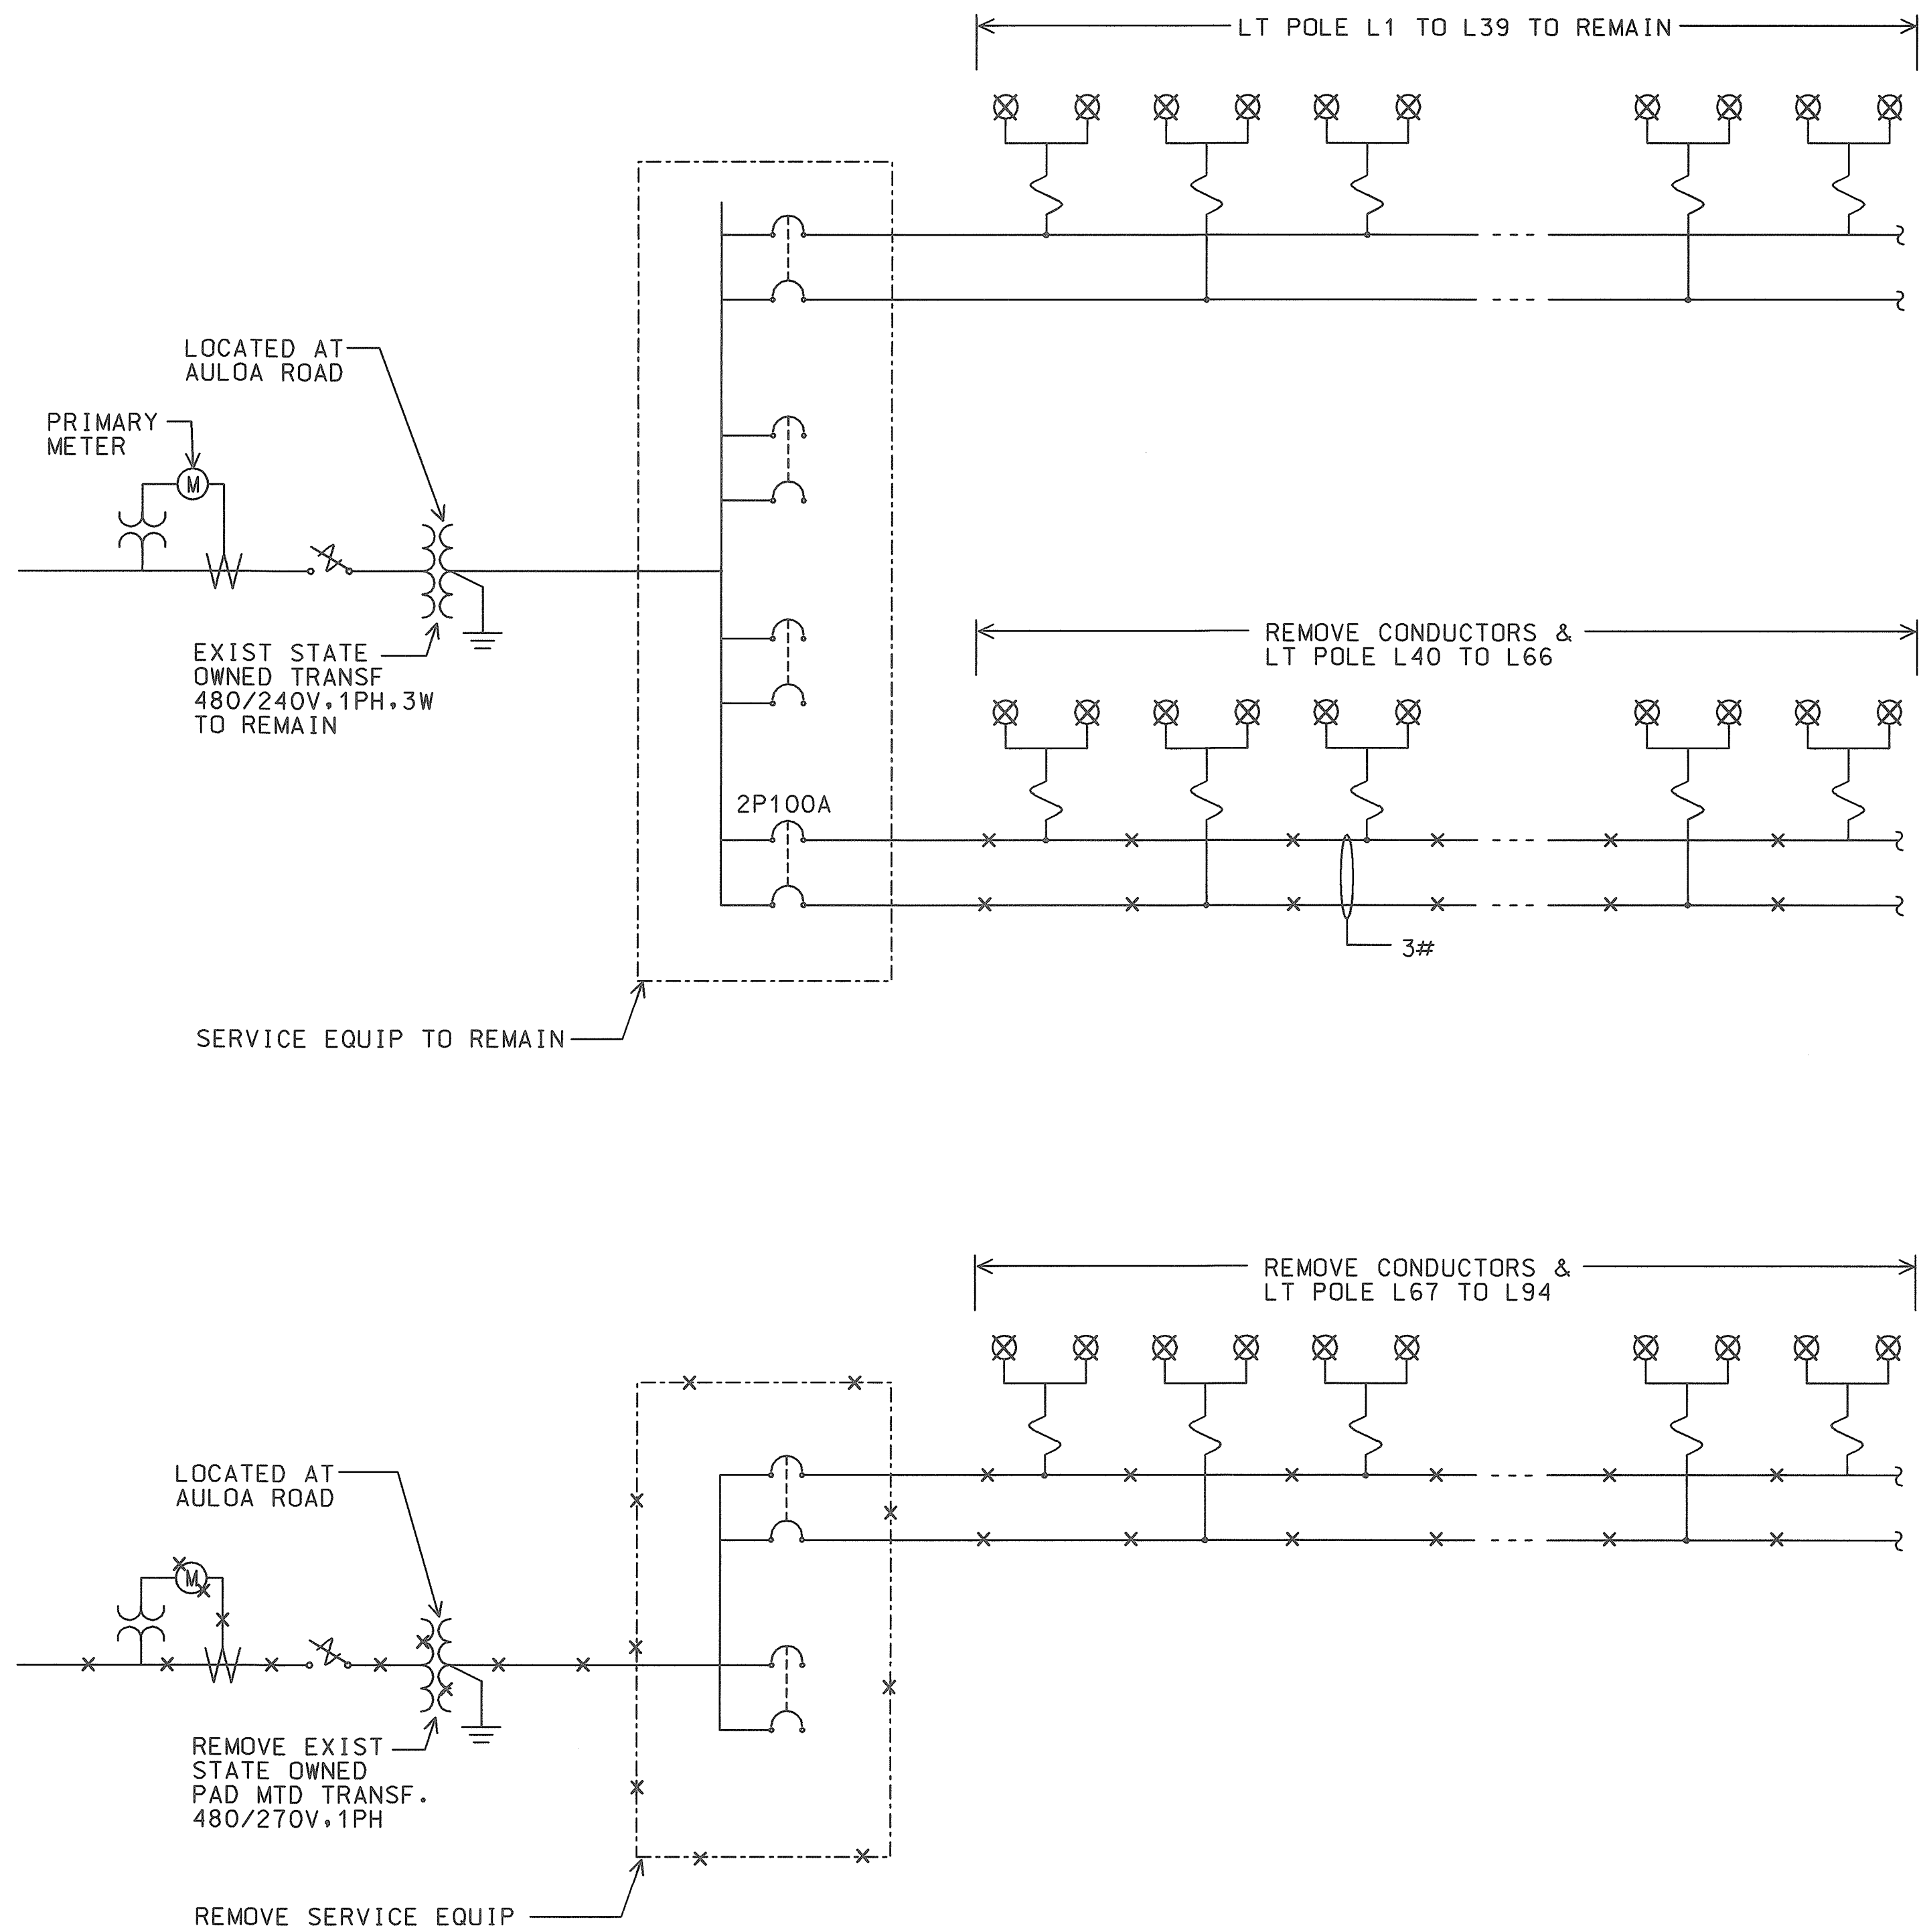

EXISTING ONE-LINE DIAGRAM
98058-3L



AS-BUILT
2/4/03
DATE

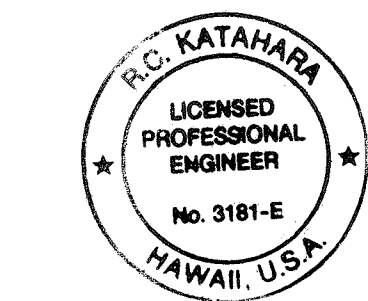

THIS WORK WAS PREPARED BY ME
OR UNDER MY SUPERVISION.
PC/Kalishan 4/25/98
MK ENGINEERS, LTD.

STATE OF HAWAII
DEPARTMENT OF TRANSPORTATION
HIGHWAYS DIVISION
EXISTING ONE-LINE DIAGRAM
HIGHWAY LIGHTING SAFETY IMPROVEMENTS
KALANIANA'OLE HIGHWAY
VICINITY OF CASTLE JUNCTION TO WAIMANALO JUNCTION
FEDERAL AID PROJ. NO. STP-0300(66)
SCALE: AS NOTED DATE: DECEMBER 1998
SHEET No. E10 OF 56 SHEETS

FED. ROAD DIST. NO.	STATE	FED. AID PROJ. NO.	FISCAL YEAR	SHEET NO.	TOTAL SHEETS
HAWAII	HAW.	STP-0300(66)	1998	12	

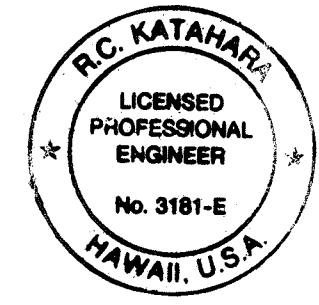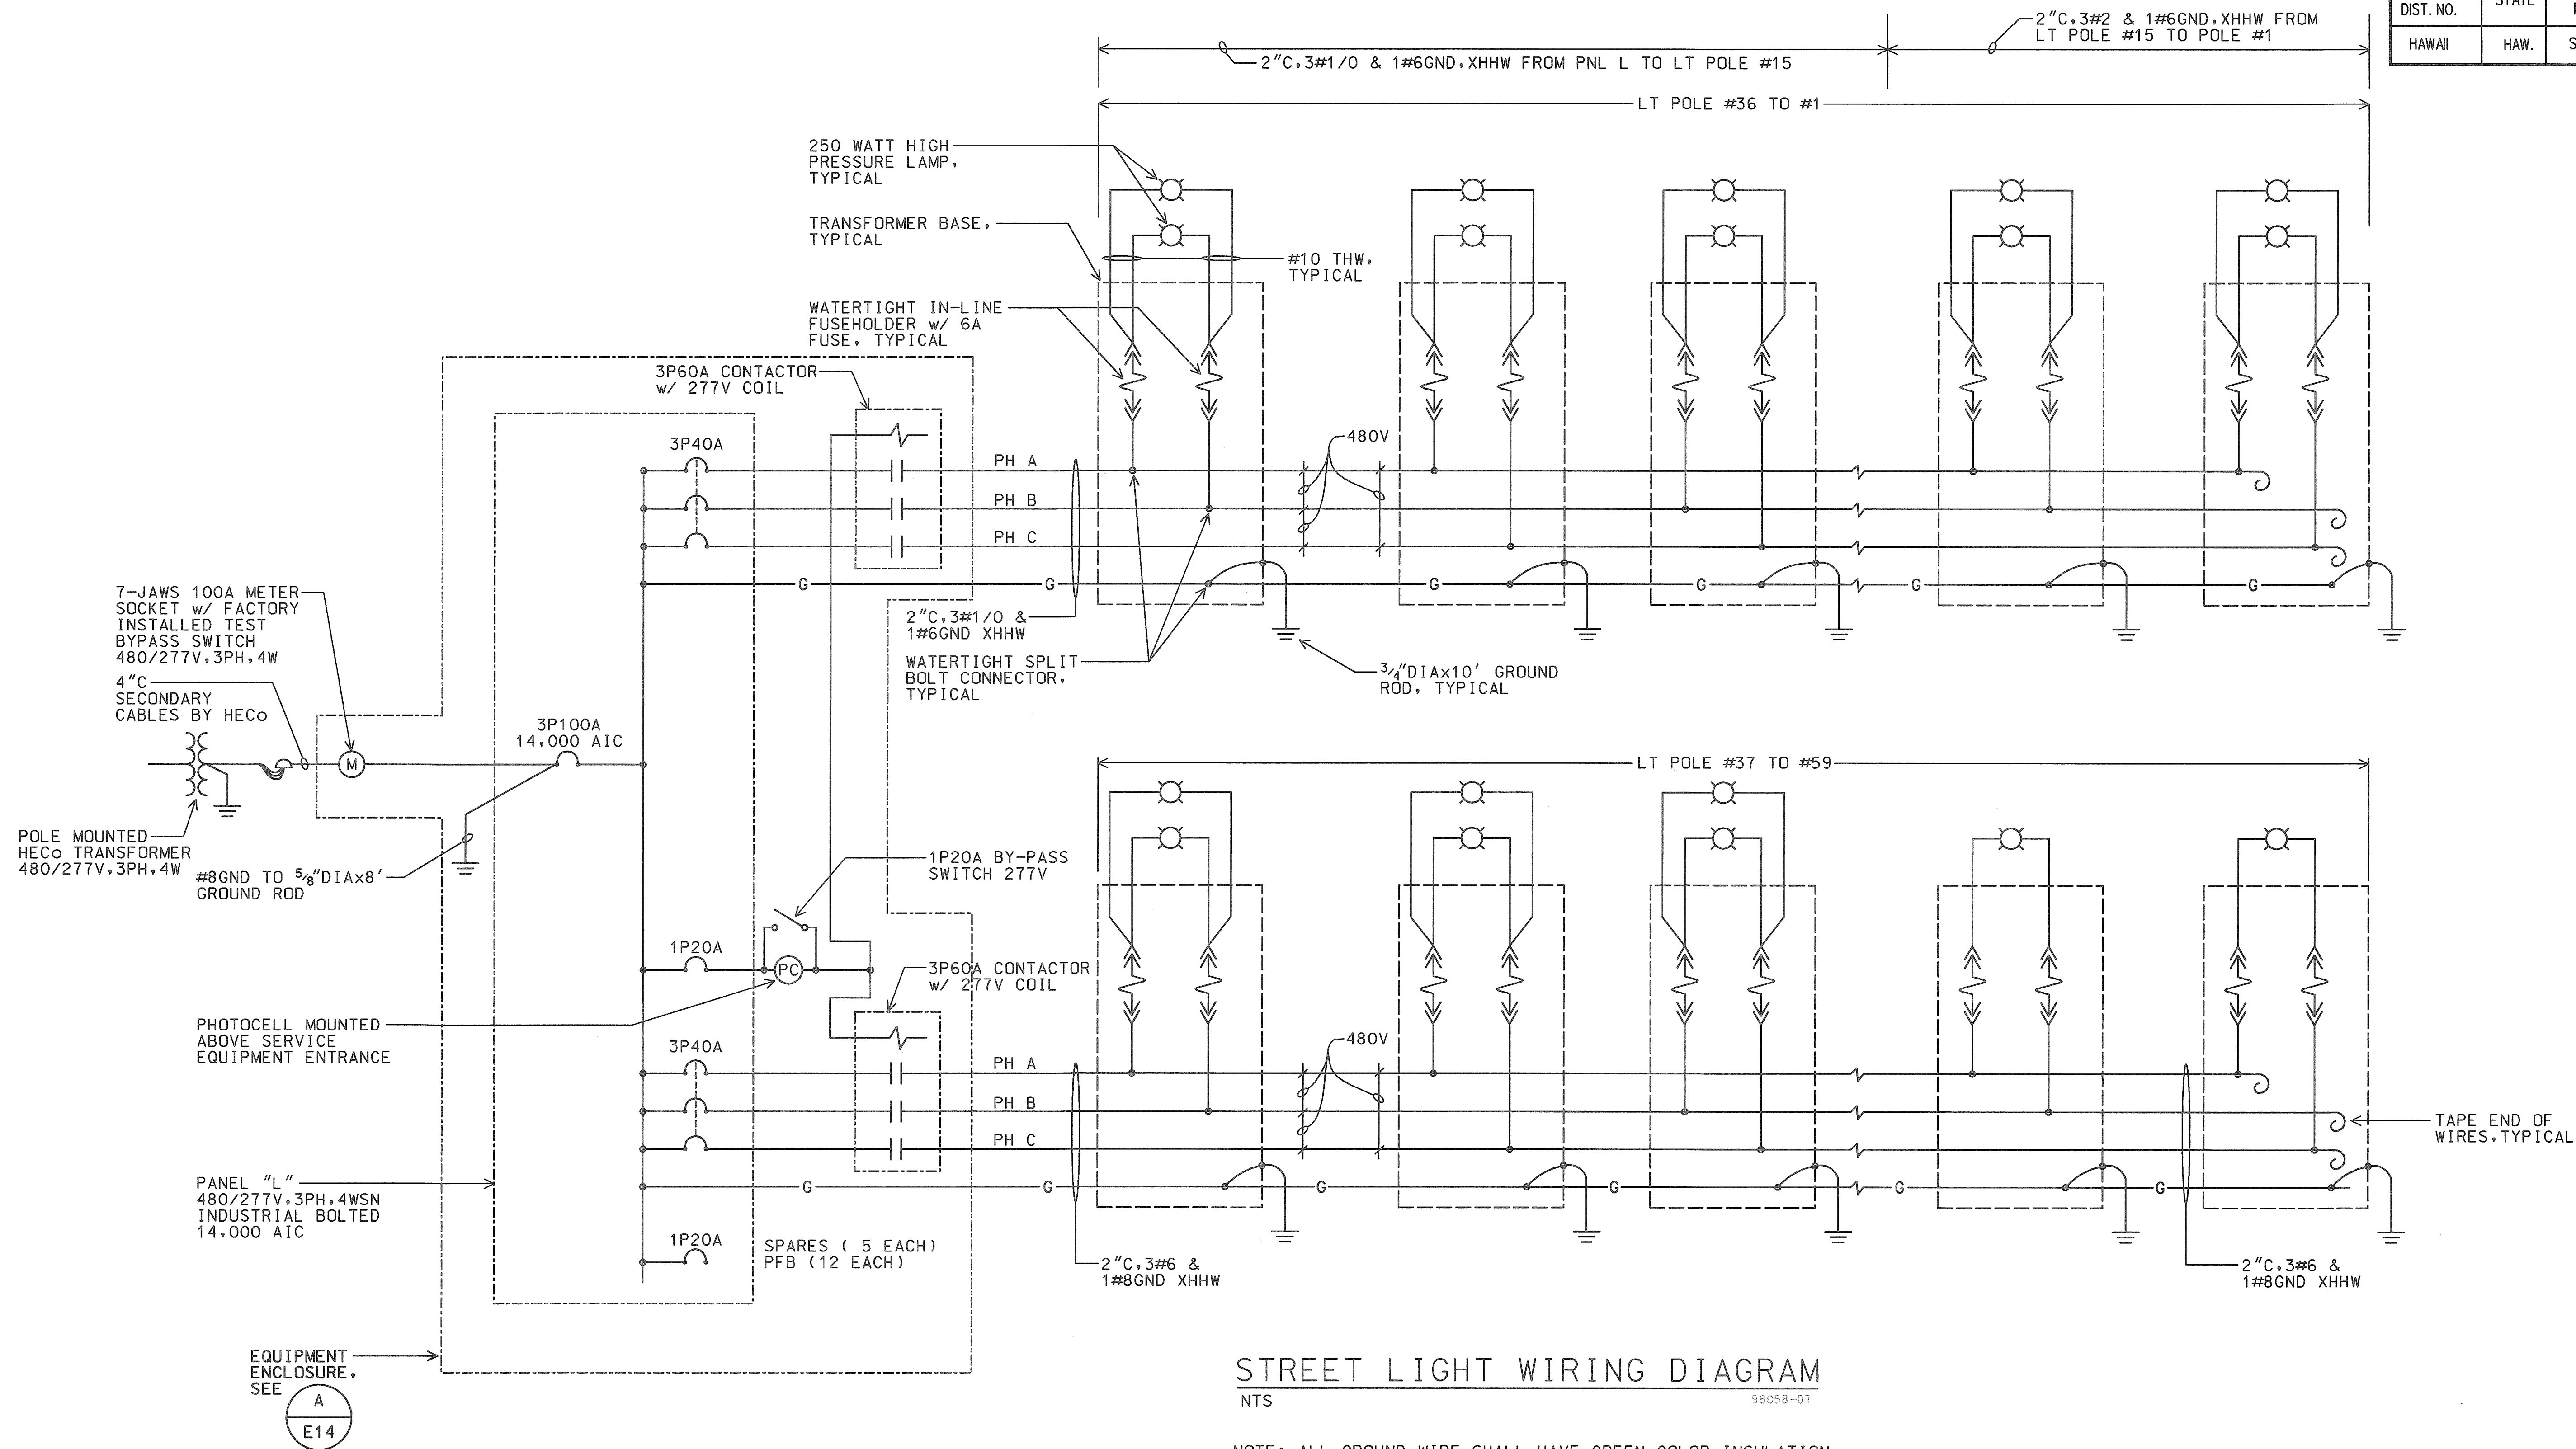

THIS WORK WAS PREPARED BY ME
OR UNDER MY SUPERVISION.
R.C. KATAHARA 11/25/98
MK ENGINEERS, LTD.

STATE OF HAWAII
DEPARTMENT OF TRANSPORTATION
HIGHWAYS DIVISION


STREET LIGHT WIRING DIAGRAM

HIGHWAY LIGHTING SAFETY IMPROVEMENTS
KALANIANA'OLE HIGHWAY
VICINITY OF CASTLE JUNCTION TO WAIMANALO JUNCTION
FEDERAL AID PROJ. NO. STP-0300(66)


SCALE: AS NOTED DATE: DECEMBER 1998
SHEET No. E12 OF 56 SHEETS

AS-BUILT
9/4/03
DATE

FED. ROAD DIST. NO.	STATE	FED. AID PROJ. NO.	FISCAL YEAR	SHEET NO.	TOTAL SHEETS
HAWAII	HAW.	STP-0300(66)	1998	13	

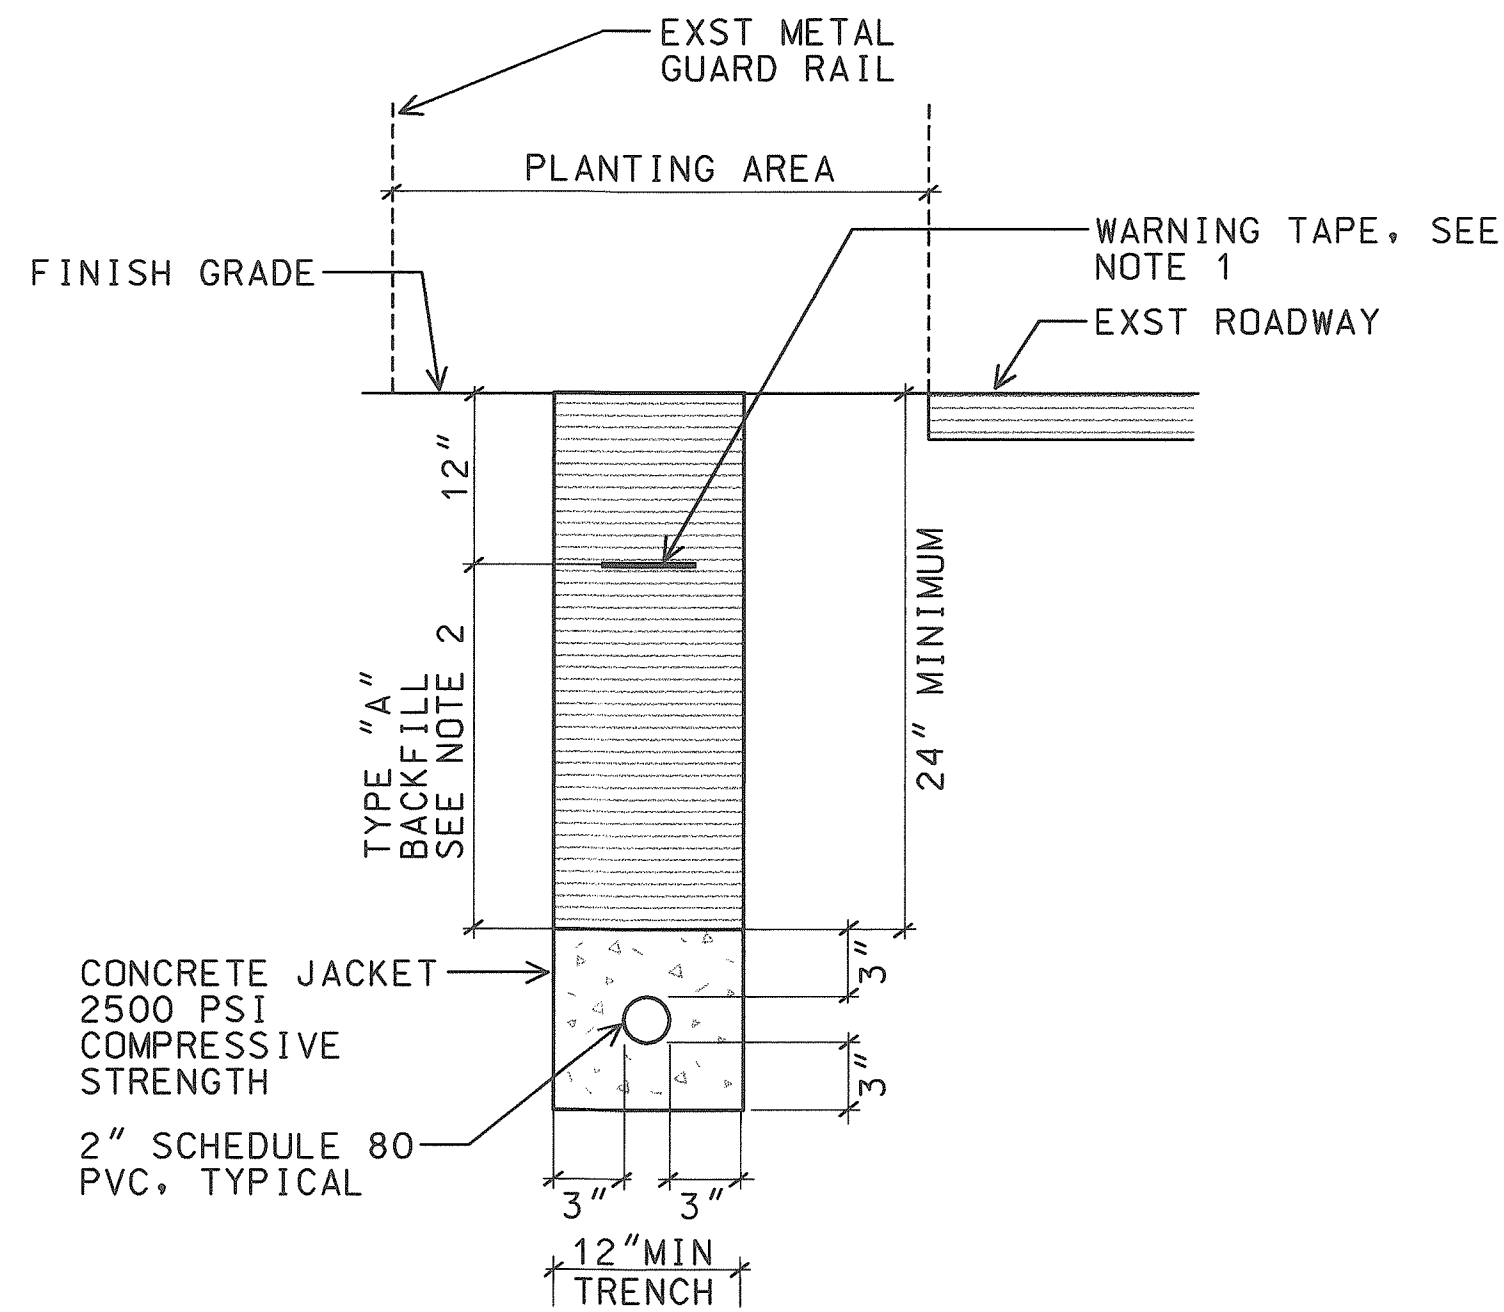


A
E13 CONCRETE ENCASED (NON ROADWAY AREA)
NTS 98058-DD

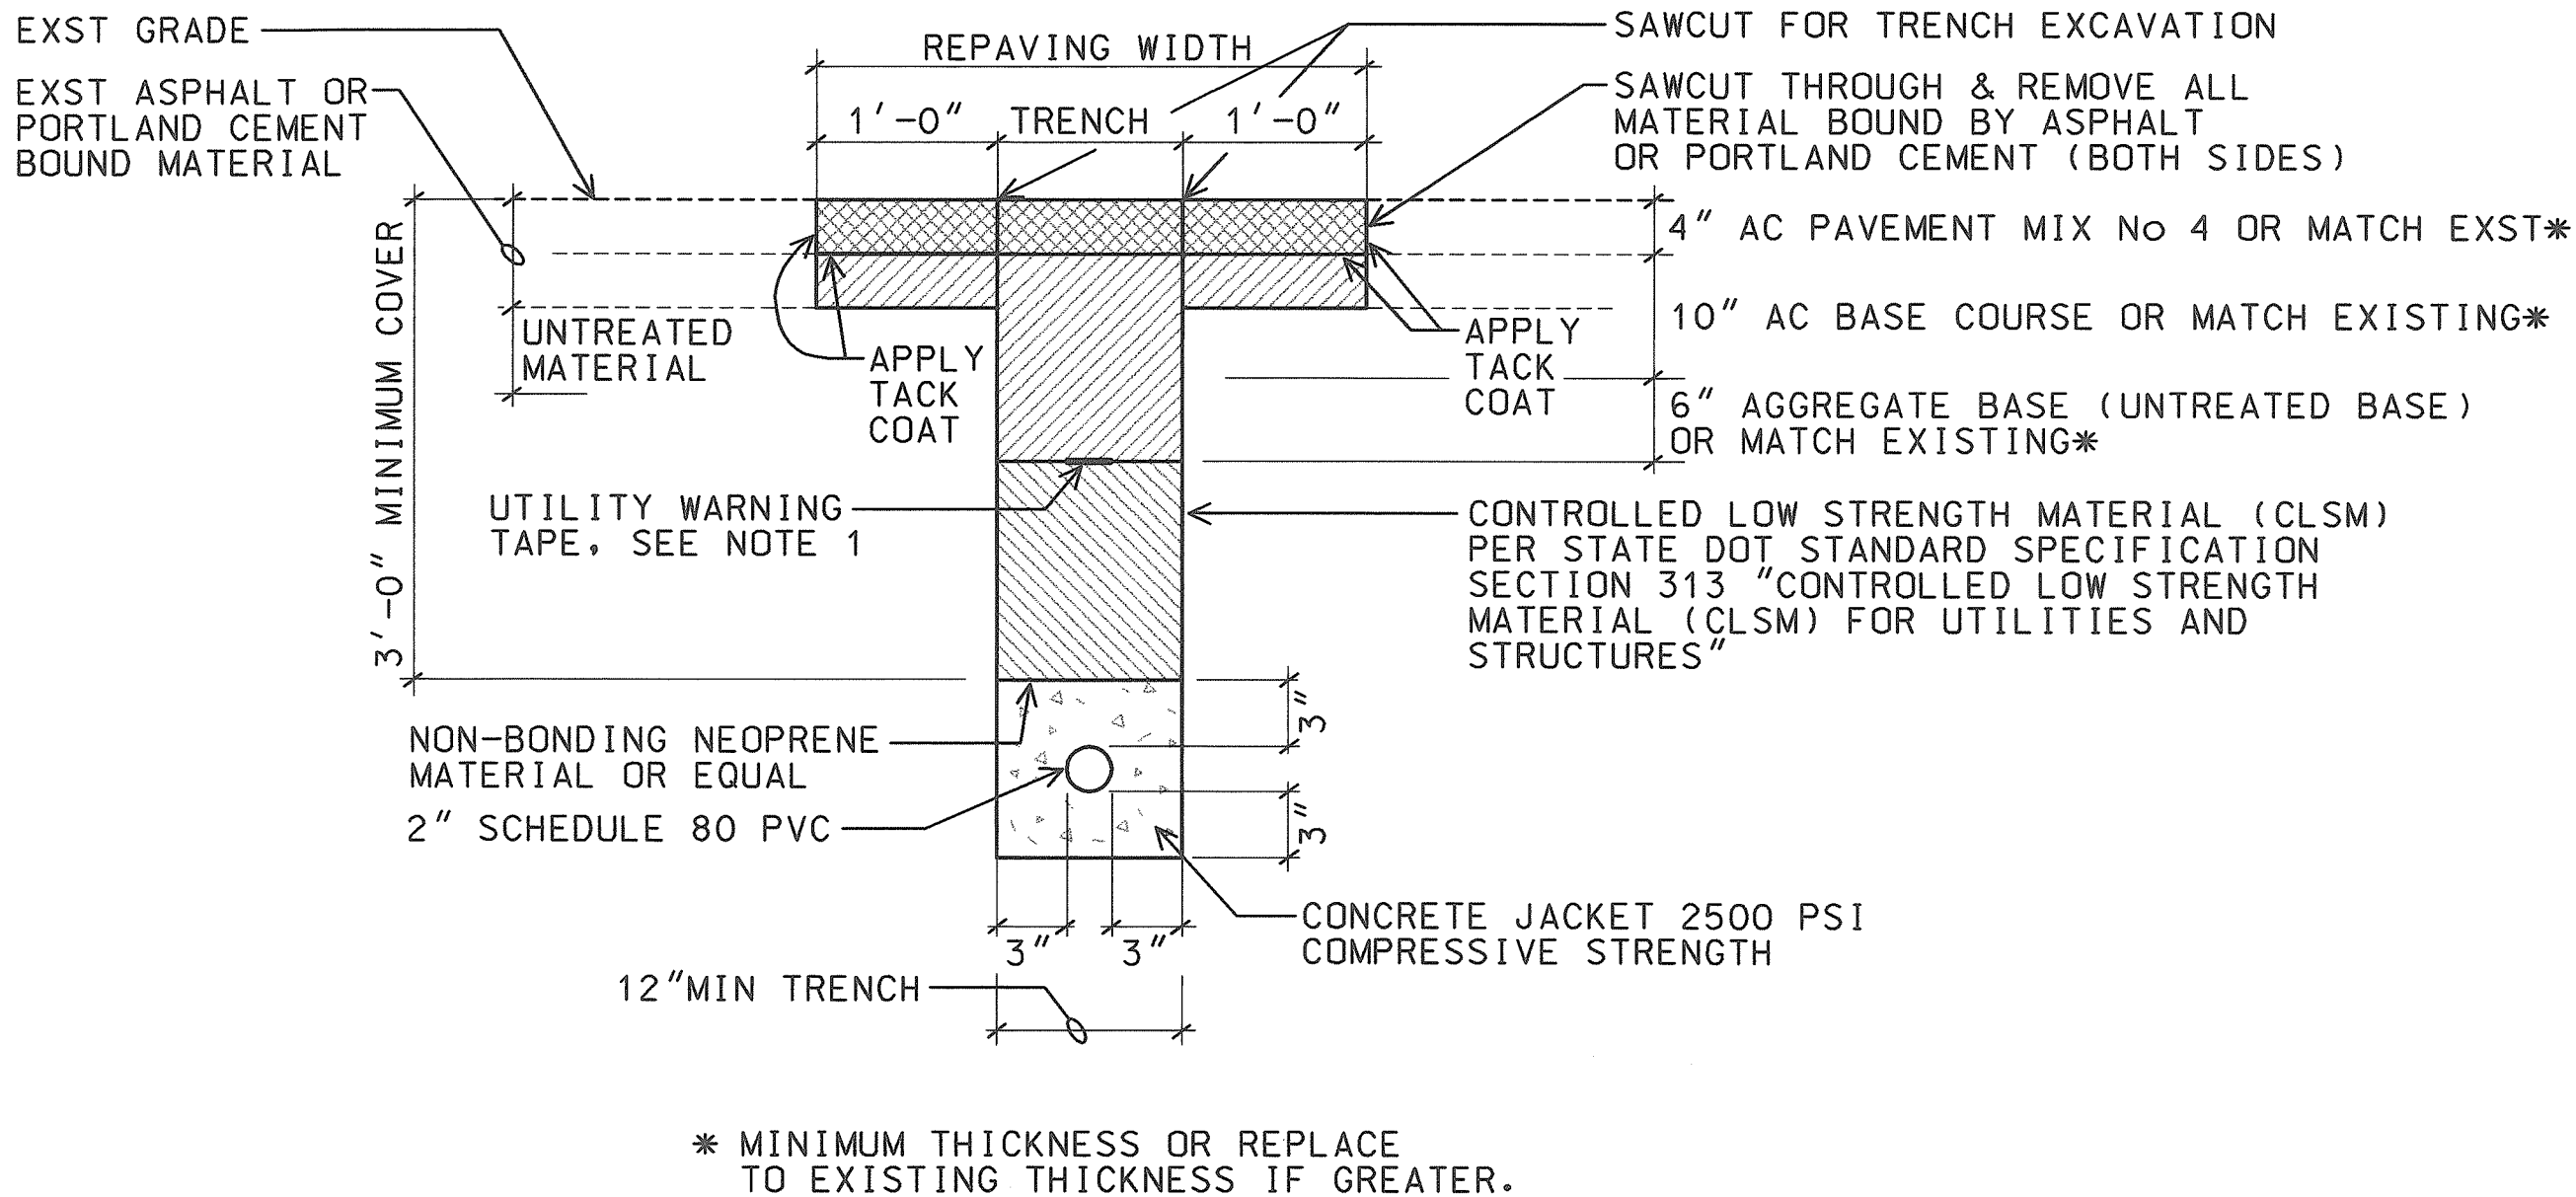


B
E13 TYPICAL PAVEMENT RESTORATION IN STATE HIGHWAY
NTS 98058-DD

- NOTES:**
- 8 MIL THICK RED COLORED PLASTIC WARNING TAPE 3" WIDE, ENTIRE LENGTH OF DUCT. TAPE TO HAVE CONTINUOUS METALLIC BACKING AND CORROSION RESISTANT FOIL CORE. WARNING AND IDENTIFICATION TO BE IMPRINTED ON TAPE AND SHALL READ "CAUTION BURIED ELECTRIC CABLE BELOW". MESSAGE SHALL BE REPEATED APPROXIMATELY EVERY TEN FEET.
 - TYPE "A" BACKFILL: BEACH SAND, EARTH OR EARTH AND GRAVEL USED, THE MAXIMUM ROCK SIZE SHALL BE 1" AND THE MIXTURE SHALL CONTAIN NOT MORE THAN 50% BY VOLUME OF ROCK PARTICLES.

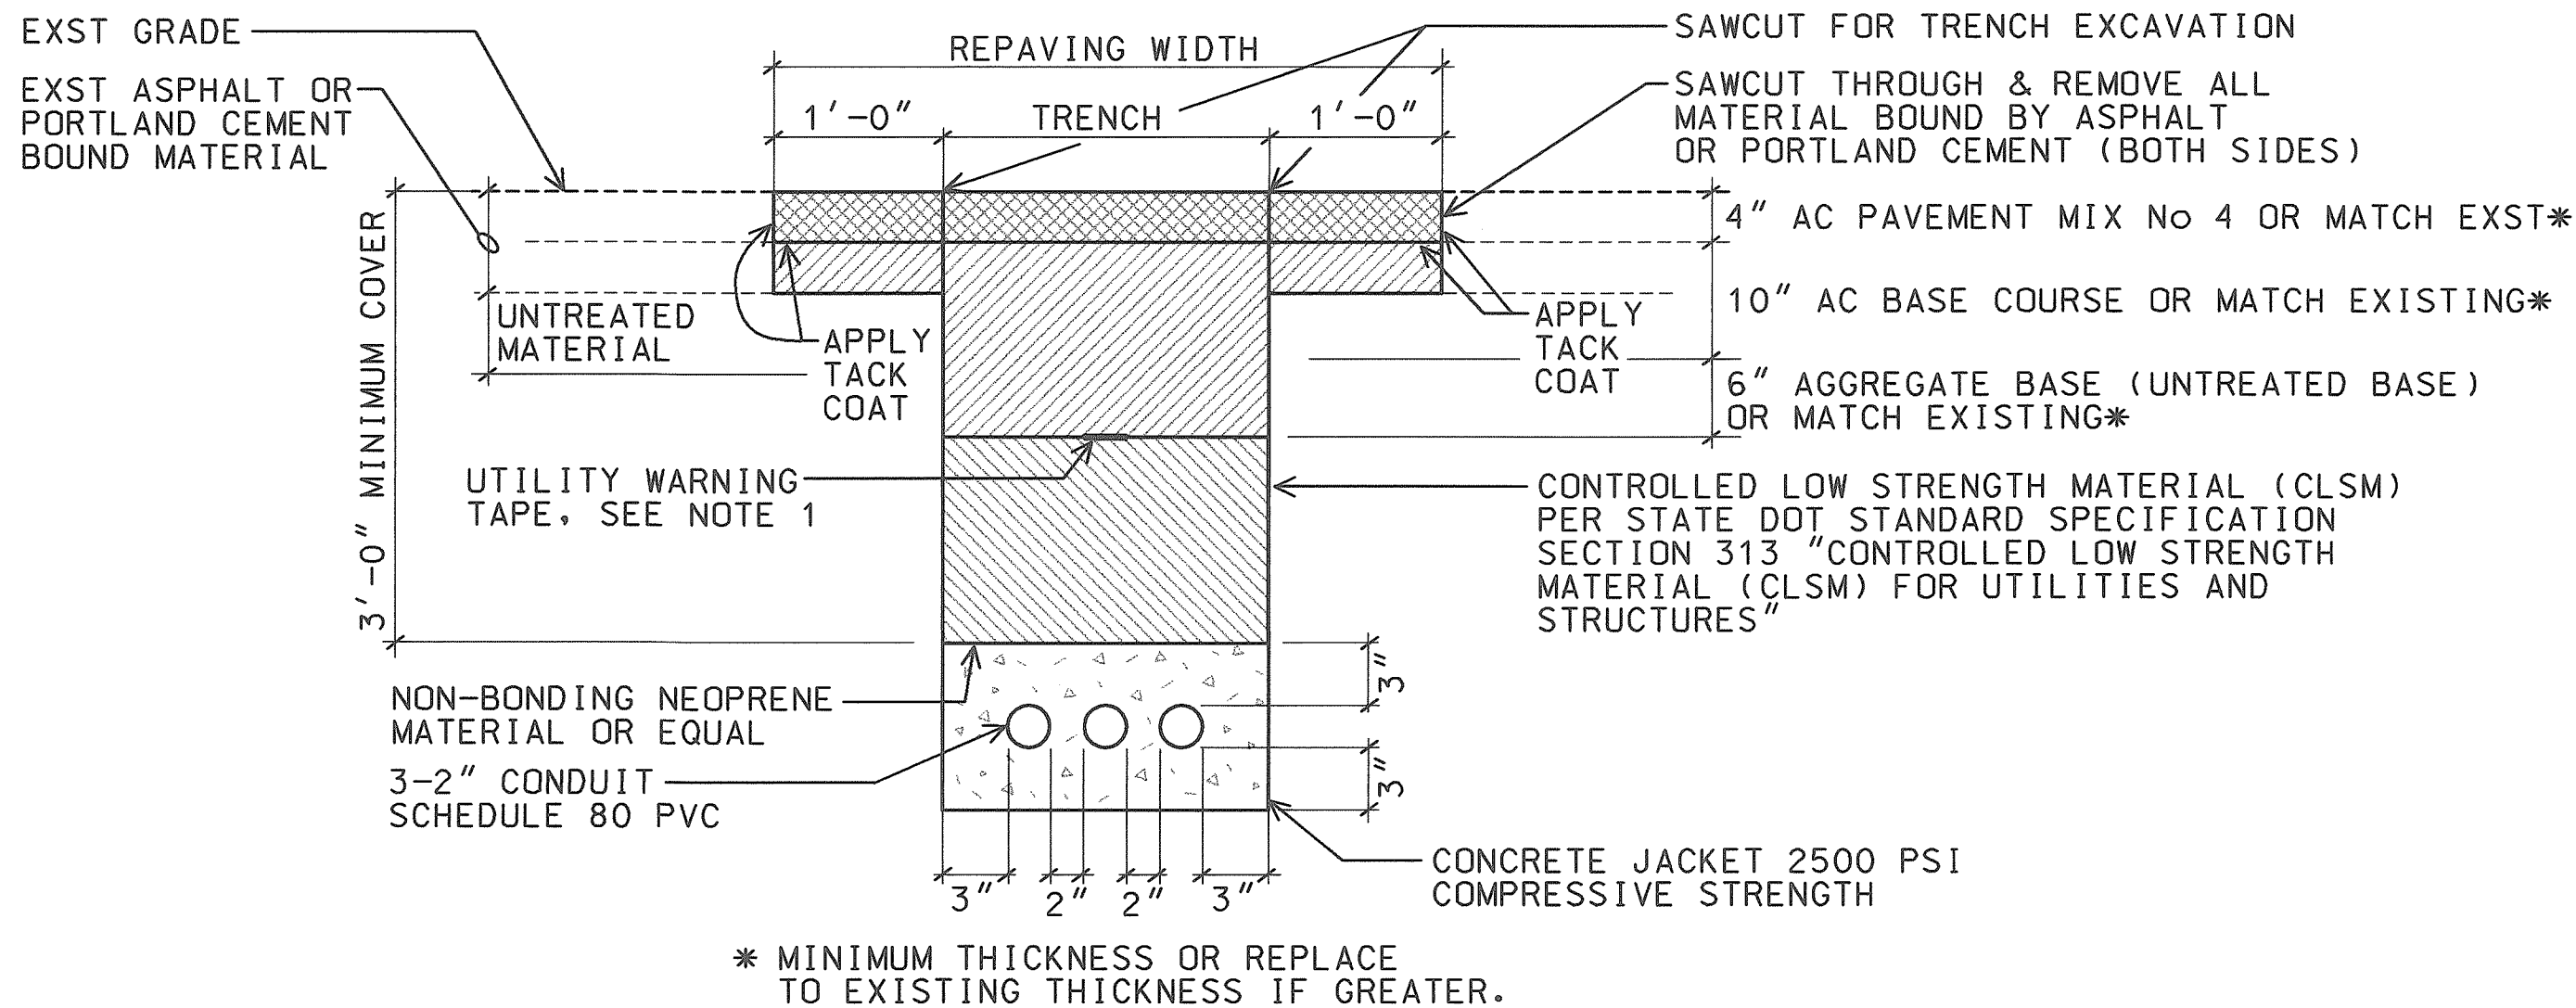


C
E13 TYPICAL PAVEMENT RESTORATION IN STATE HIGHWAY
NTS 98058-DD

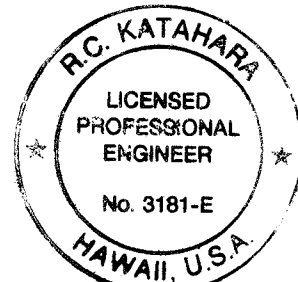

THIS WORK WAS PREPARED BY ME
OR UNDER MY SUPERVISION.
R.C. KATAHARA
MK ENGINEERS, LTD.





DATE	REV	DESCRIPTION
8/16/99	1	REV. WARNING TAPE
STATE OF HAWAII DEPARTMENT OF TRANSPORTATION HIGHWAYS DIVISION DUCT SECTIONS HIGHWAY LIGHTING SAFETY IMPROVEMENTS KALANIANAOLE HIGHWAY VICINITY OF CASTLE JUNCTION TO WAIMANALO JUNCTION FEDERAL AID PROJ. NO. STP-0300(66)		
SCALE: AS NOTED		DATE: DECEMBER 1998
SHEET No. <u>E13</u> OF <u>56</u> SHEETS		

FED. ROAD DIST. NO.	STATE	FED. AID PROJ. NO.	FISCAL YEAR	SHEET NO.	TOTAL SHEETS
HAWAII	HAW.	STP-0300(66)	1998	14	

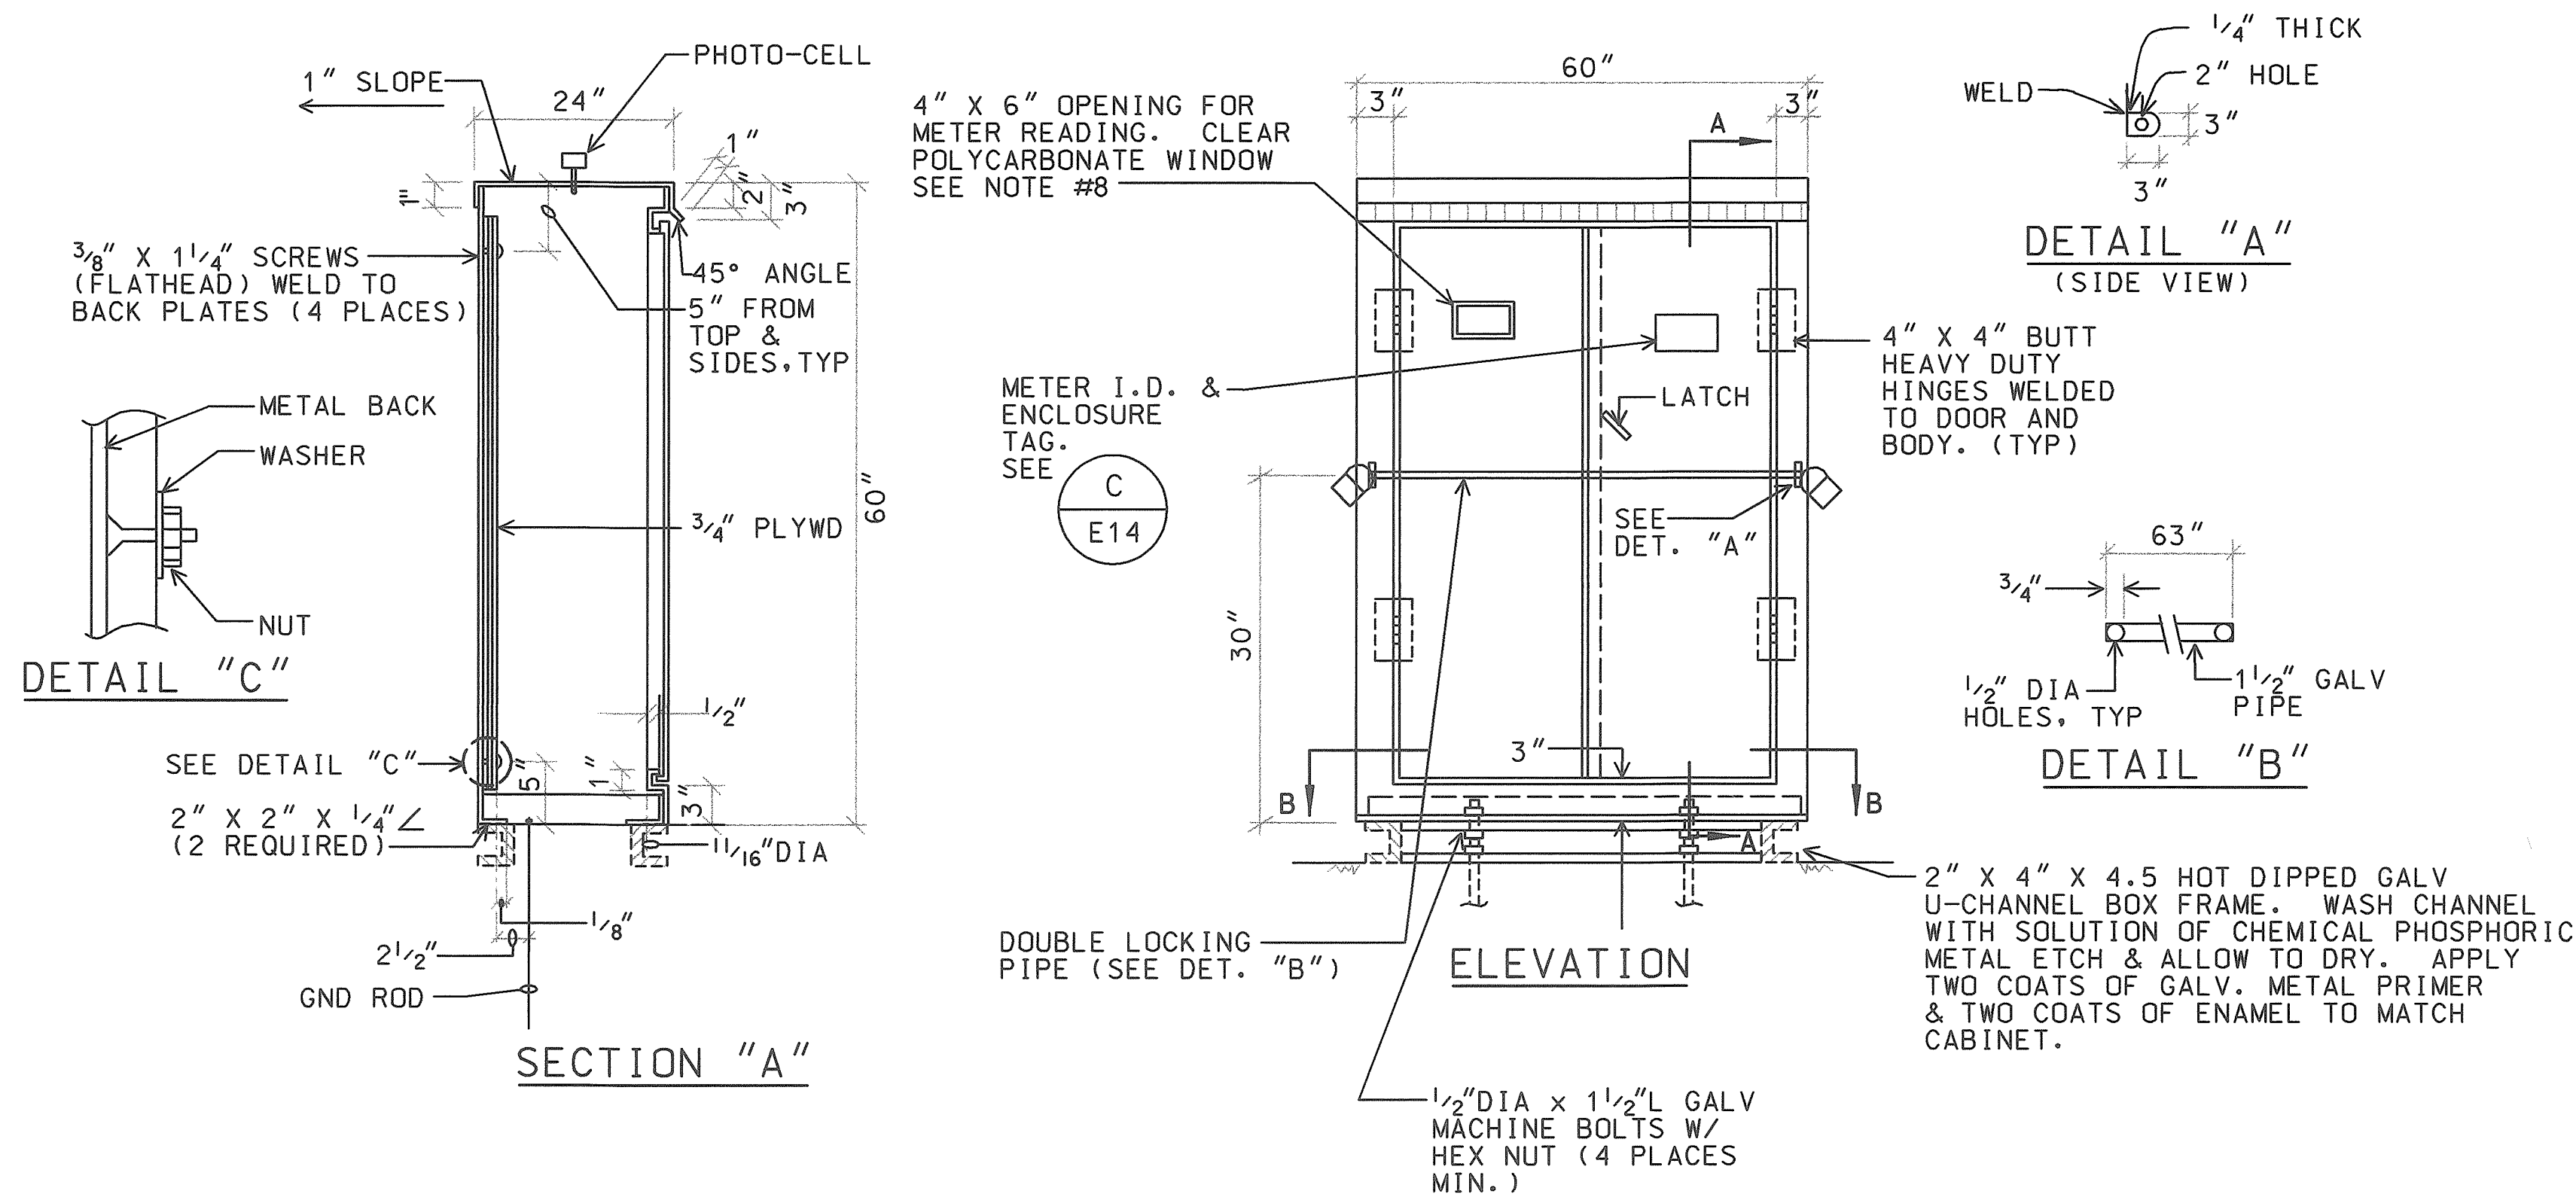


NOTES:

- CABINET TO BE PRIMED WITH ONE COAT SHOP PRIMER.
- PLYWOOD TO BE 3/4" THICK (MIN.) TREATED (WOLMANIZED) PLYWOOD. (EXTERIOR GRADE)
- MADE FROM 10 GAUGE ALUMINUM.
- PROVIDE ACRYLIC ENAMEL FINISH, COLOR TO MATCH TRANSFORMER. (2 COATS)
- ENCLOSURE SHALL BE NEMA 3R WITH NEOPRENE GASKETING.
- PADLOCKS:
 - 1-HECO FURNISHED
 - 1-CONTRACTOR FURNISHED, BRASS CORBIN SESAME COMBINATION
- SHOP FABRICATION DRAWINGS SHALL BE SUBMITTED FOR APPROVAL.
- LOCATION OF OPENING FOR METER READER TO CORRESPOND WITH LOCATION OF METER.

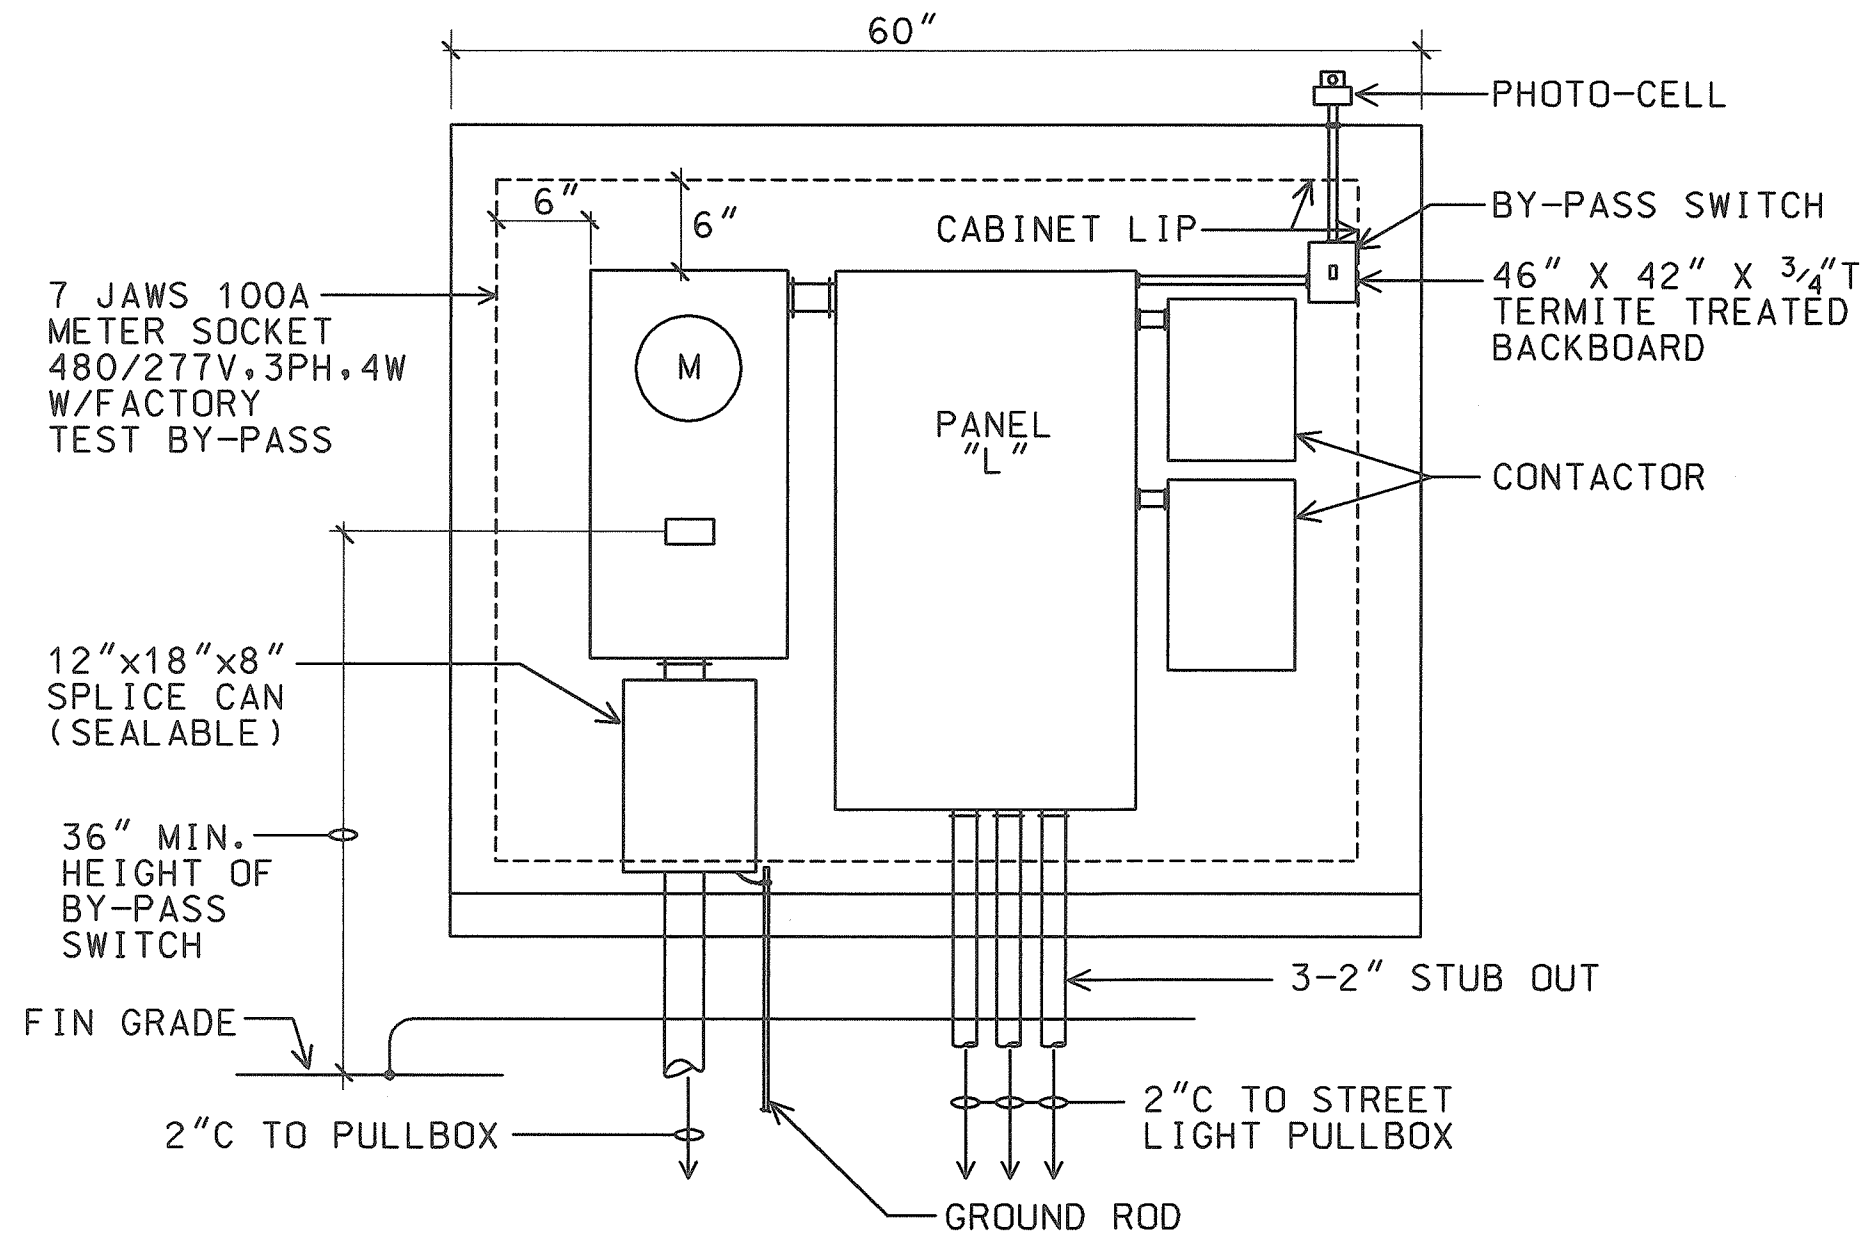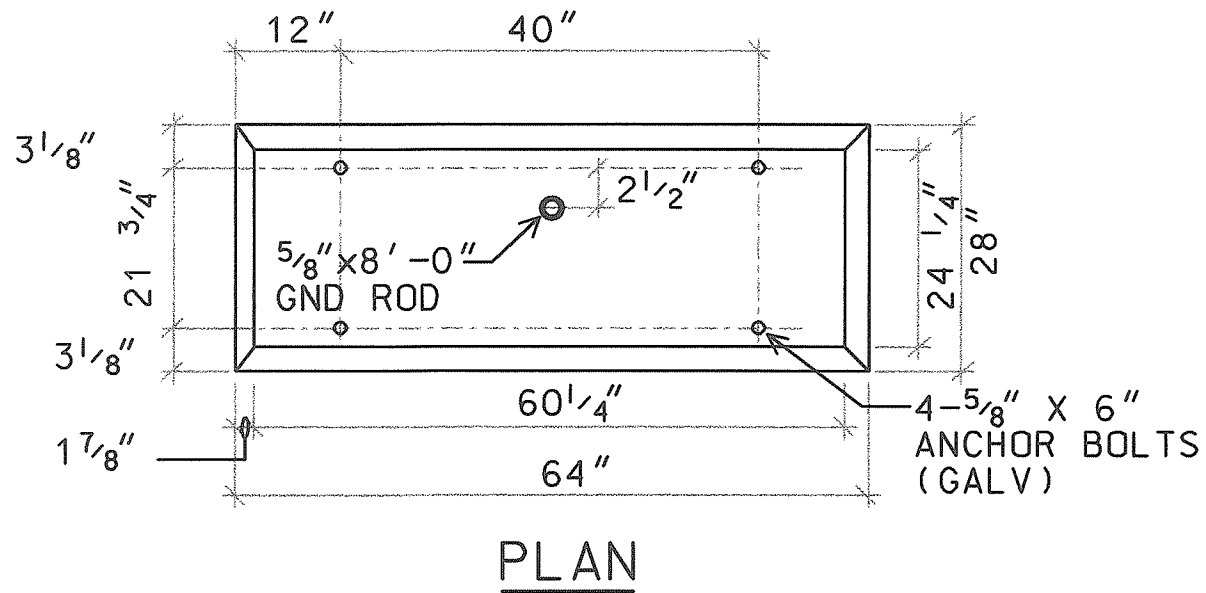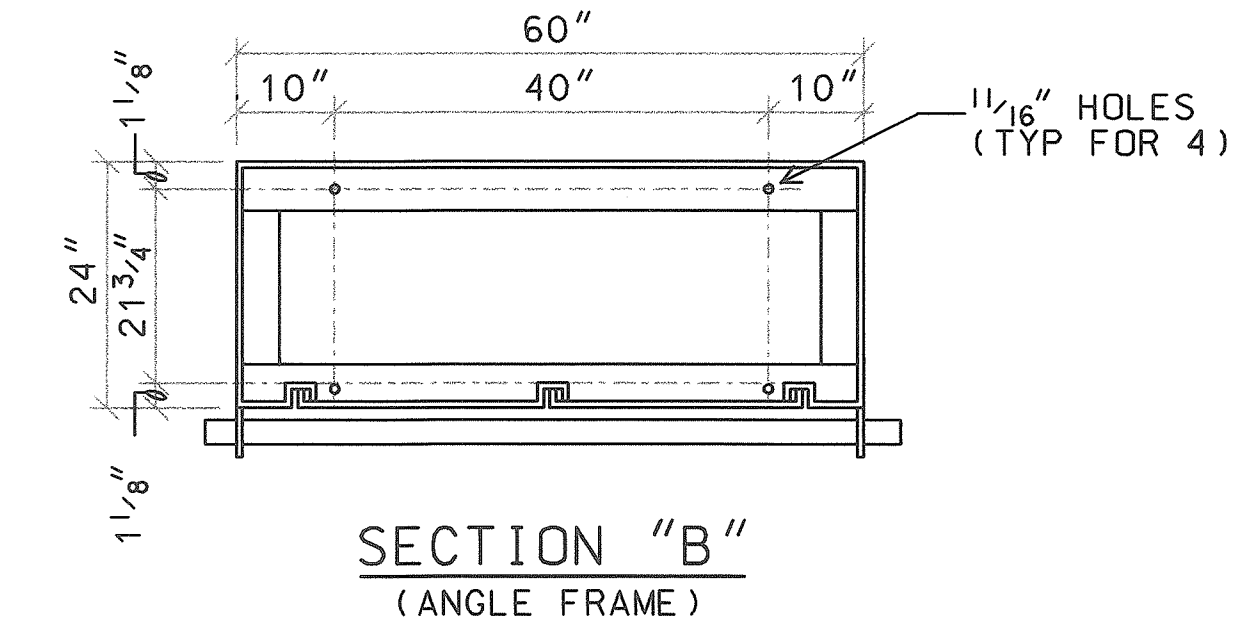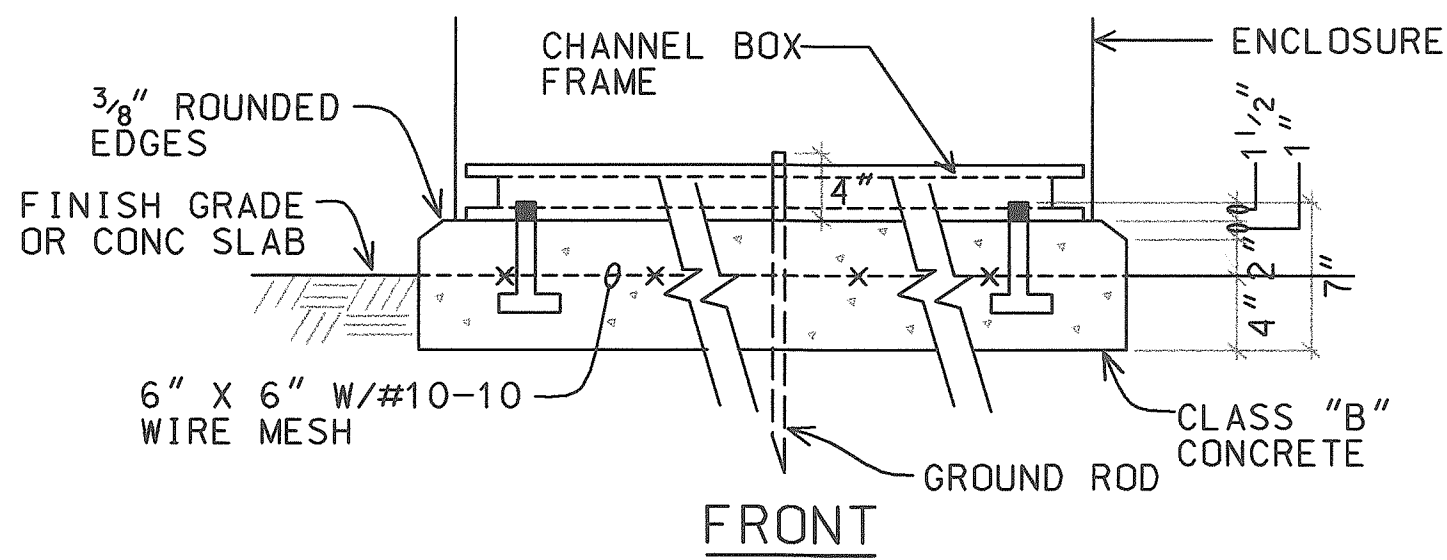

B EQUIPMENT ELEVATION
E14 NTS 98059-08

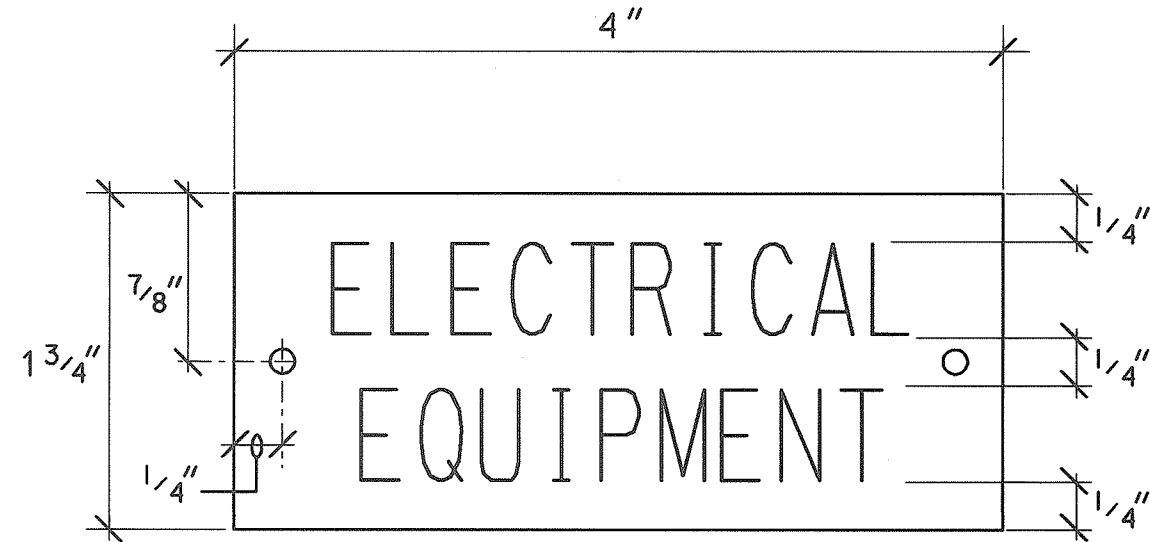


NOTES:

- USE 2 PLY PLASTIC - BLACK, WHITE.
- LETTER SIZE SHALL BE 1/2" HIGH AND ENGRAVED 1/16" WIDE, WHITE IN COLOR.
- ATTACH TO EQUIPMENT ENCLOSURE WITH NO.7 STAINLESS STEEL DRIVE SCREWS.

C METER EQUIPMENT ID TAG DETAIL
E14 NTS 98058-0C

A METER AND EQUIPMENT CABINET
E14 NTS 98058-0A

CONCRETE PAD


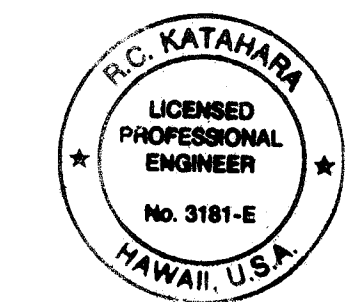


THIS WORK WAS PREPARED BY ME
OR UNDER MY SUPERVISION.
R.C. KATAHARA 11/25/98
RKC ENGINEERS LTD.

STATE OF HAWAII DEPARTMENT OF TRANSPORTATION HIGHWAYS DIVISION METER DETAILS HIGHWAY LIGHTING SAFETY IMPROVEMENTS KALANIANA'OLE HIGHWAY VICINITY OF CASTLE JUNCTION TO WAIMANALO JUNCTION FEDERAL AID PROJ. NO. STP-0300(66)
SCALE: AS NOTED DATE: DECEMBER 1998 SHEET No. E14 OF 56 SHEETS

AS-BUILT
2/4/03

FED. ROAD DIST. NO.	STATE	FED. AID PROJ. NO.	FISCAL YEAR	SHEET NO.	TOTAL SHEETS
HAWAII	HAW.	STP-0300(66)	1998		

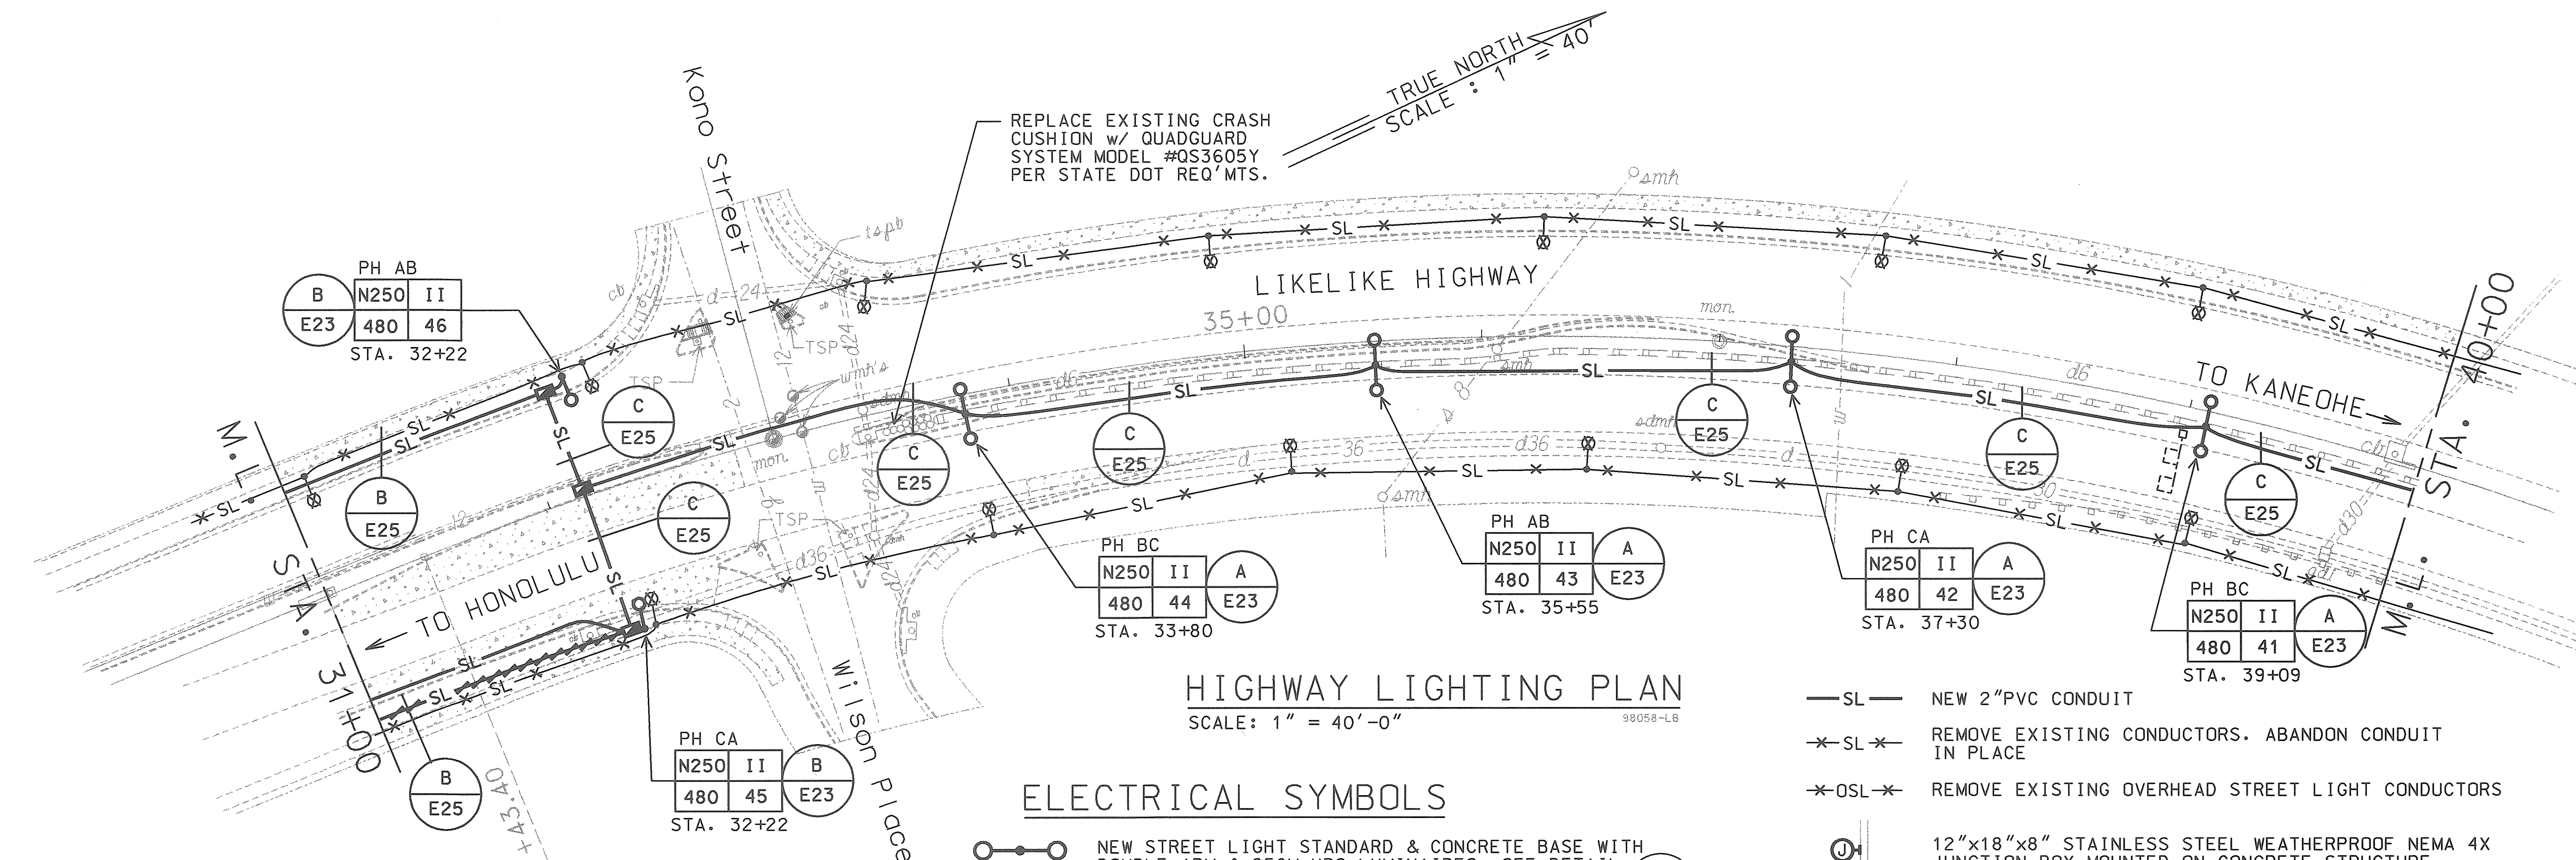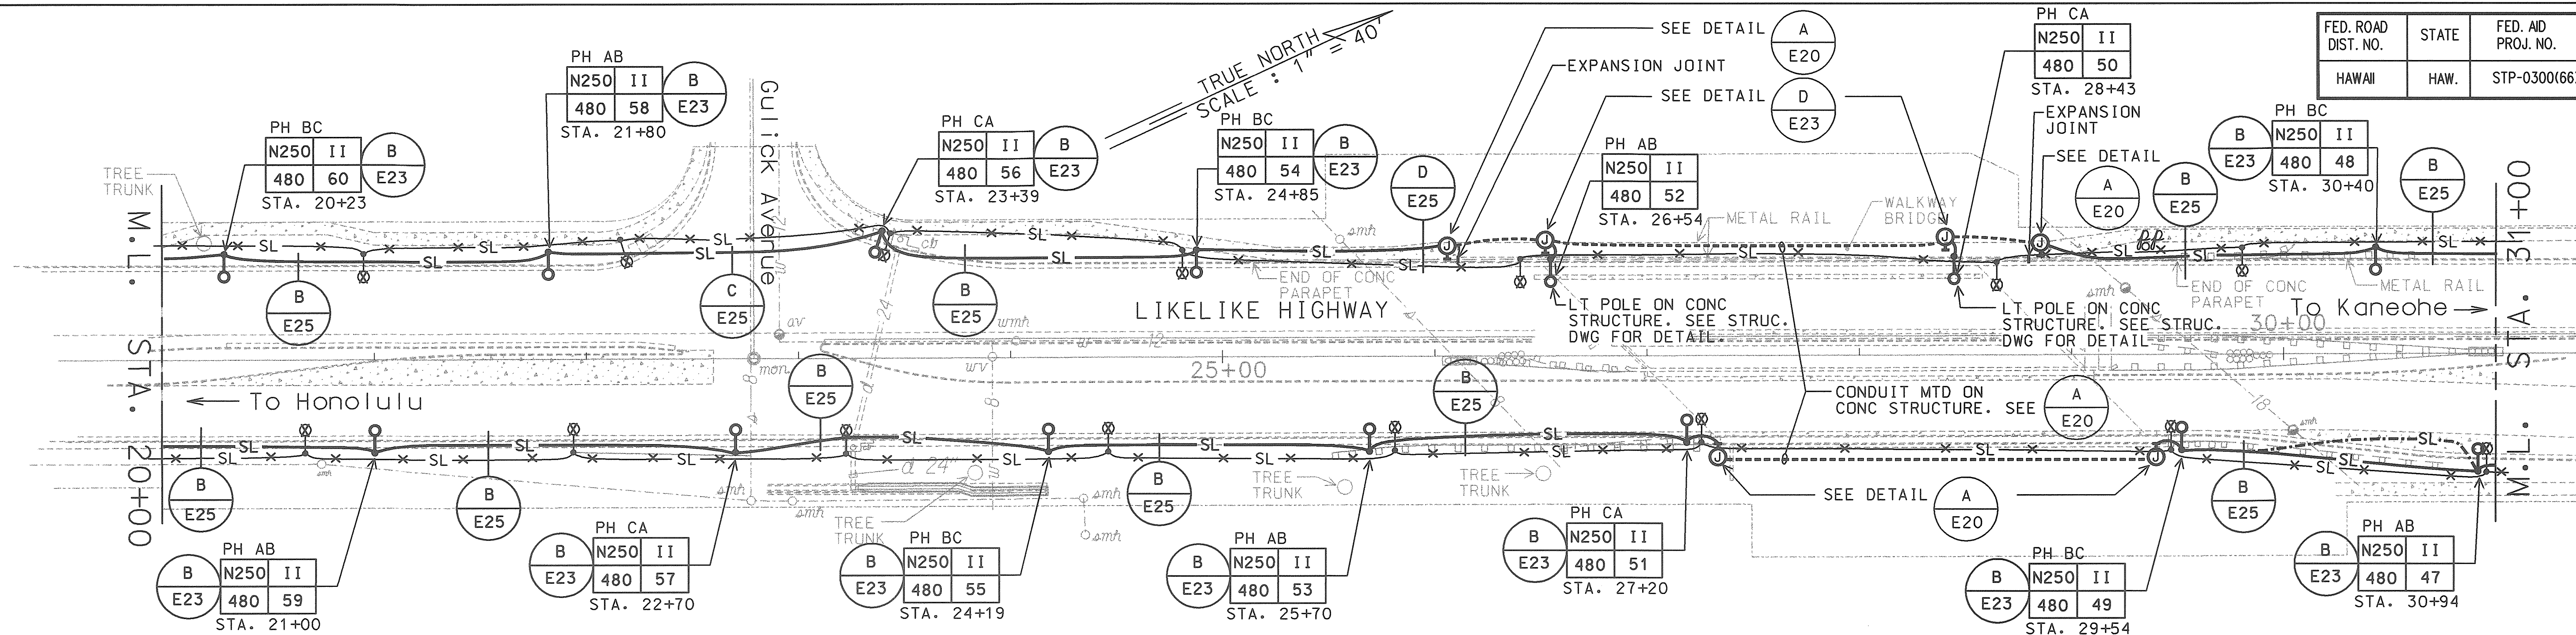


HIGHWAY LIGHTING PLAN SCALE: 1" = 40'-0"

ELECTRICAL SYMBOLS

- NEW STREET LIGHT STANDARD & CONCRETE BASE WITH DOUBLE ARM & 250W HPS LUMINAIRES. SEE DETAIL
- STREET LIGHT PULLBOX. SEE DETAIL
- NEW STREET LIGHT STANDARD & CONCRETE BASE WITH SINGLE ARM & 250W HPS LUMINAIRE. SEE DETAIL
- REMOVE EXISTING STREET LIGHT POLE. DEMOLISH CONCRETE BASE 24" BELOW FINISH GRADE.
- EXISTING STREET LIGHT LUMINAIRE & BRACKET ARM ON WOOD POLE
- REMOVED EXISTING STREET LIGHT POLE. DEMOLISH CONCRETE BASE 24" BELOW FINISH GRADE

- SL — NEW 2" PVC CONDUIT
- SL — REMOVE EXISTING CONDUCTORS. ABANDON CONDUIT IN PLACE
- OSL — REMOVE EXISTING OVERHEAD STREET LIGHT CONDUCTORS
- 12"x18"x8" STAINLESS STEEL WEATHERPROOF NEMA 4X JUNCTION BOX MOUNTED ON CONCRETE STRUCTURE

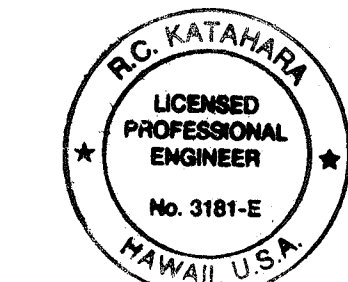


THIS WORK WAS PREPARED BY ME OR UNDER MY SUPERVISION.
DATE: 11/25/98
MK ENGINEERS, LTD.

DATE	REV	DESCRIPTION
8/16/99	A	REV. CONC BASE DEMO TO 24" BFG


STATE OF HAWAII
DEPARTMENT OF TRANSPORTATION
HIGHWAYS DIVISION
HIGHWAY LIGHTING PLAN
HIGHWAY LIGHTING SAFETY IMPROVEMENTS
LIKELIKE HIGHWAY FROM
SCHOOL STREET TO VALLEY VIEW DRIVE
PROJECT NO. STP-0300(66)
SCALE: AS NOTED
DATE: OCTOBER 1998
SHEET No. E17 OF 56 SHEETS

FED. ROAD DIST. NO.	STATE	FED. AID PROJ. NO.	FISCAL YEAR	SHEET NO.	TOTAL SHEETS
HAWAII	HAW.	STP-0300(66)	1998		

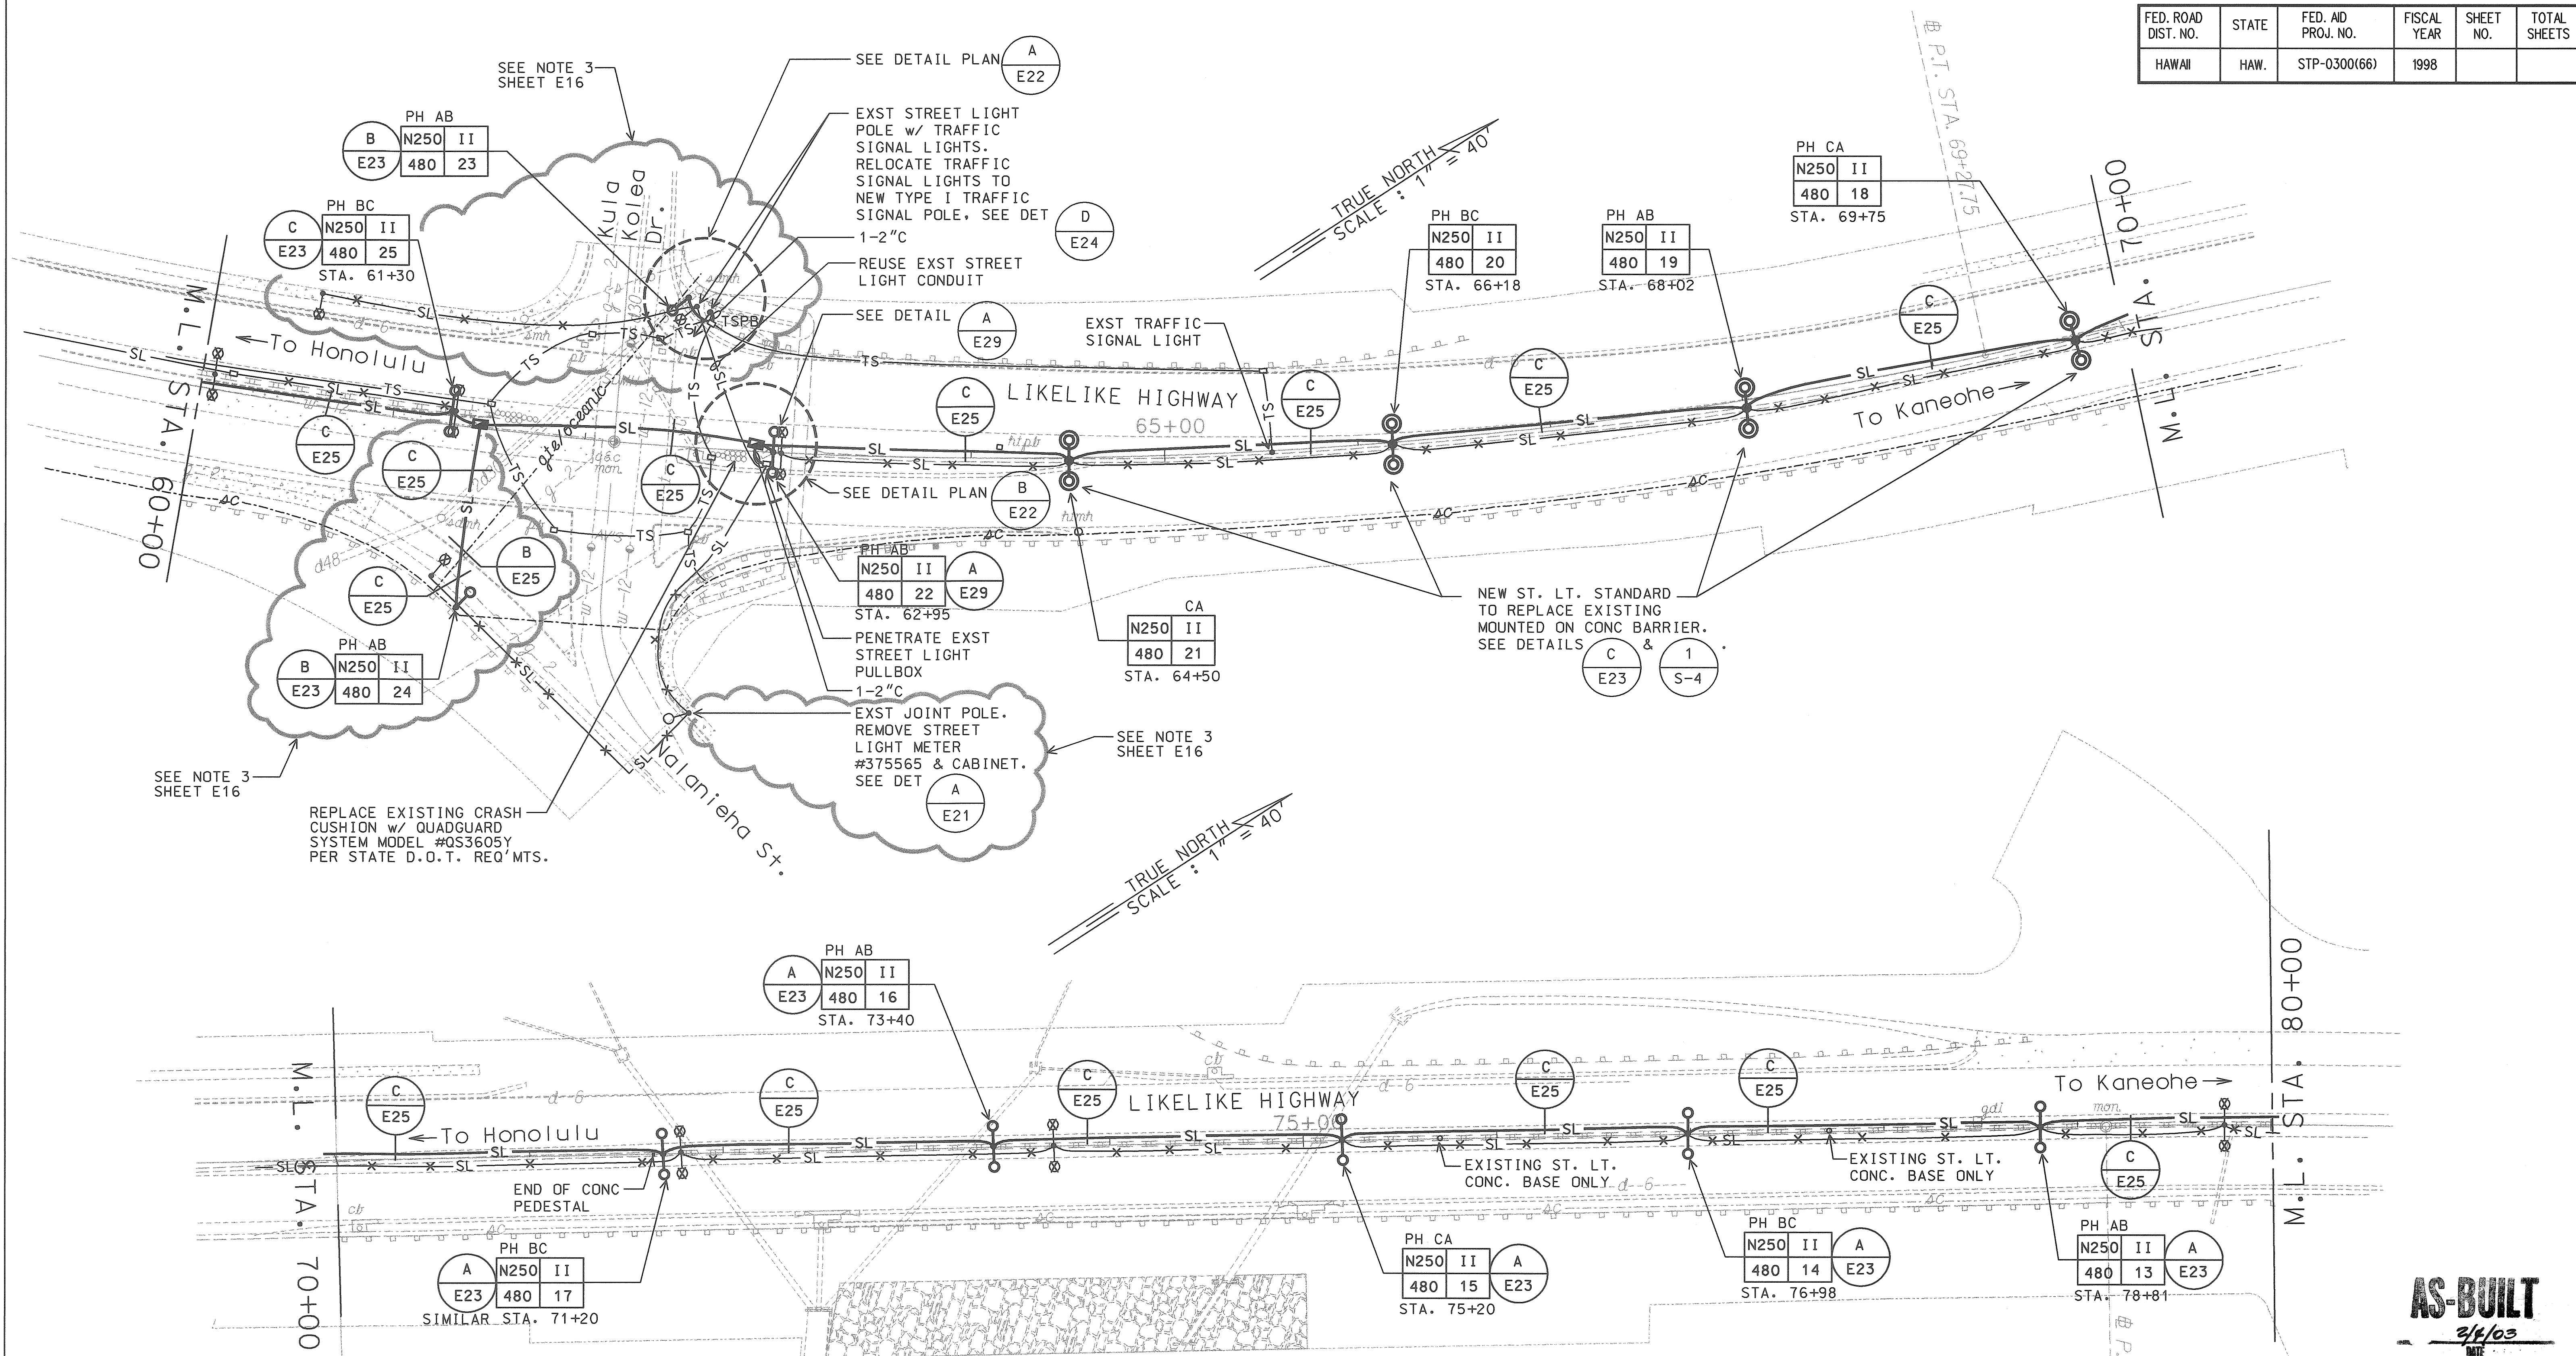

HIGHWAY LIGHTING PLAN

SCALE: 1" = 40'-0"

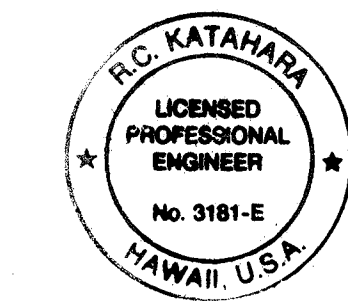

THIS WORK WAS PREPARED BY:
OR UNDER MY SUPERVISION.
R.C. KATAHARA 11/25/98
MK ENGINEERS, LTD.

STATE OF HAWAII
DEPARTMENT OF TRANSPORTATION
HIGHWAYS DIVISION

HIGHWAY LIGHTING PLAN


HIGHWAY LIGHTING SAFETY IMPROVEMENTS
LIKELINE HIGHWAY FROM
SCHOOL STREET TO VALLEY VIEW DRIVE

PROJECT NO. STP-0300(66)
SCALE: AS NOTED DATE: OCTOBER 1998
SHEET No. E19 OF 56 SHEETS


AS-BUILT
3/1/03
DATE

FED. ROAD DIST. NO.	STATE	FED. AID PROJ. NO.	FISCAL YEAR	SHEET NO.	TOTAL SHEETS
HAWAII	HAW.	STP-0300(66)	1998		


TRUE NORTH
SCALE: 1" = 40'

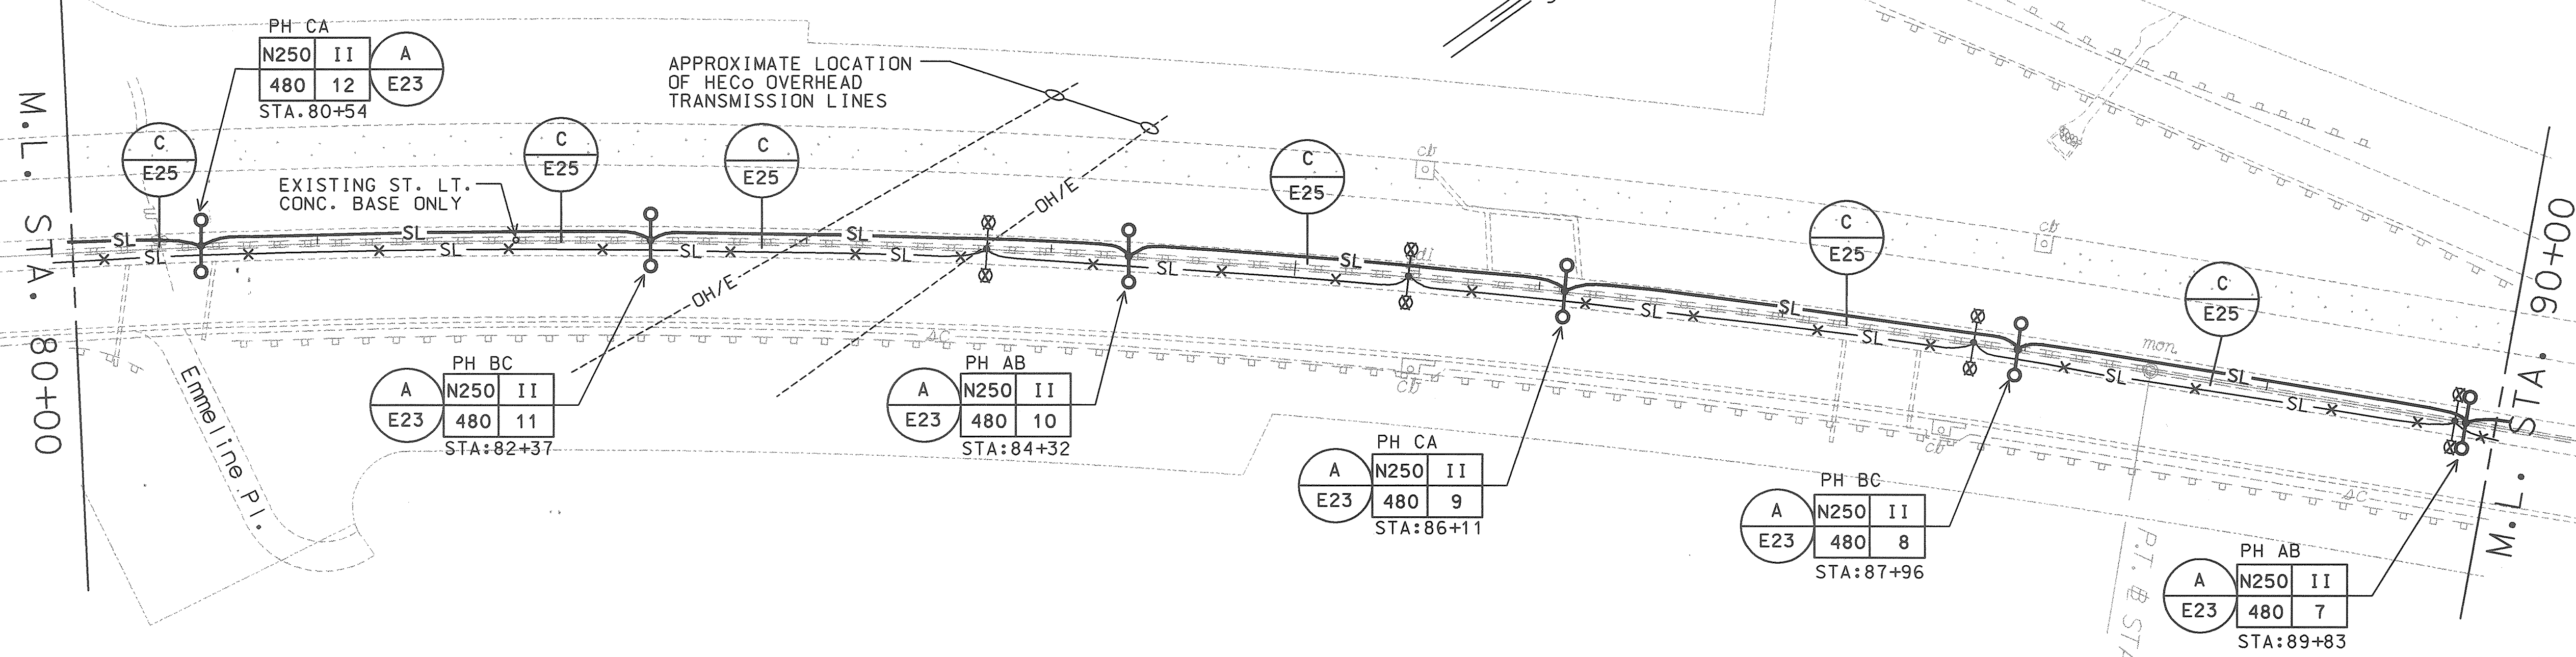

TRUE NORTH
SCALE: 1" = 40'

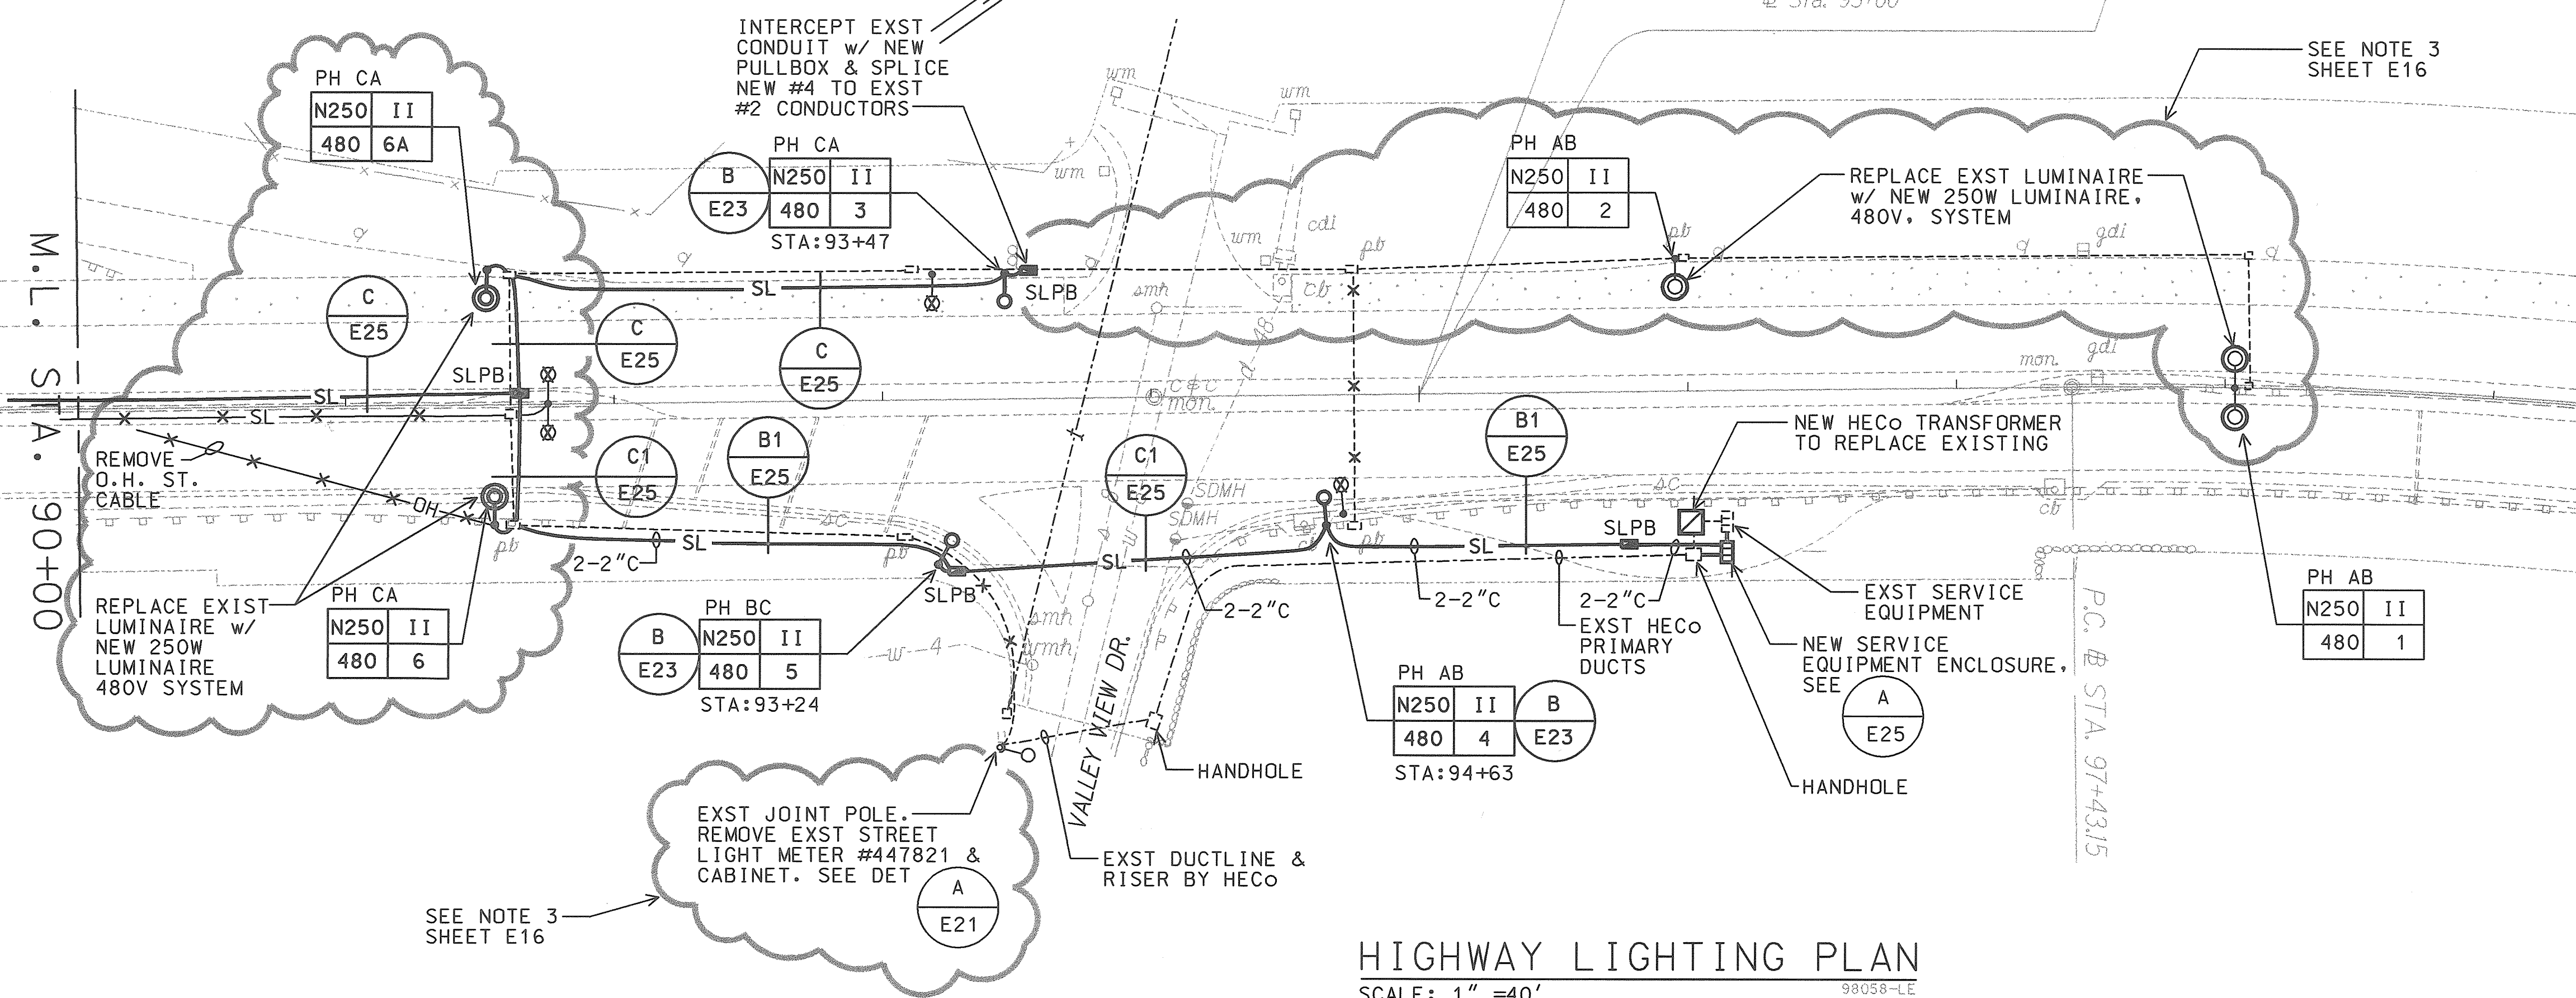


HIGHWAY LIGHTING PLAN
SCALE: 1" = 40'

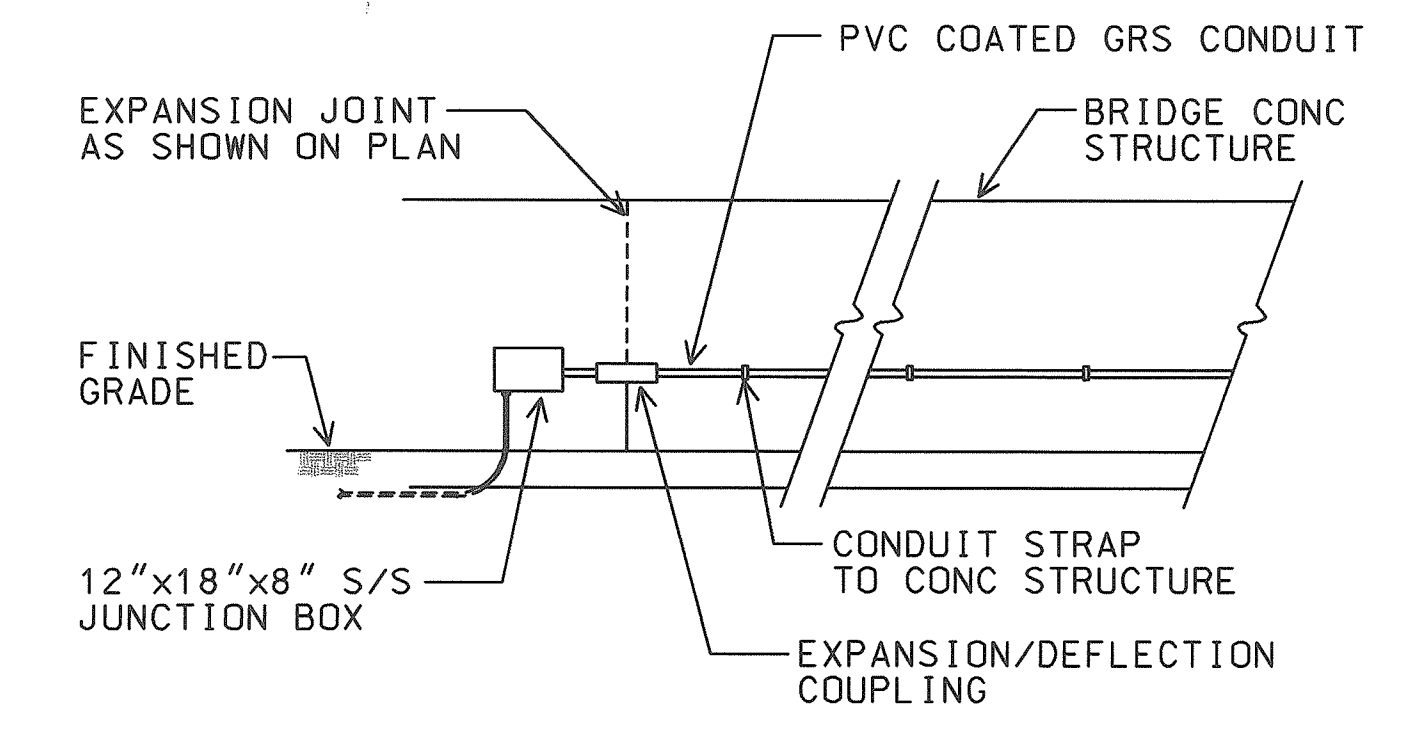

A E20 JUNCTION BOX MOUNTING DETAIL
NTS

AS-BUILT
2/4/03
DATE

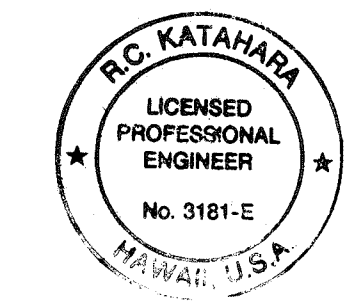

THIS WORK WAS PREPARED BY
OR UNDER MY SUPERVISION.
MK ENGINEERS, LTD.

STATE OF HAWAII
DEPARTMENT OF TRANSPORTATION
HIGHWAYS DIVISION


HIGHWAY LIGHTING PLAN

HIGHWAY LIGHTING SAFETY IMPROVEMENTS
LIKELIKE HIGHWAY FROM
SCHOOL STREET TO VALLEY VIEW DRIVE

PROJECT NO. STP-0300(66)
SCALE: AS NOTED
DATE: OCTOBER 1998

SHEET No. E20 OF 56 SHEETS

FED. ROAD DIST. NO.	STATE	FED. AID PROJ. NO.	FISCAL YEAR	SHEET NO.	TOTAL SHEETS
HAWAII	HAW.	STP-0300(66)	1998		

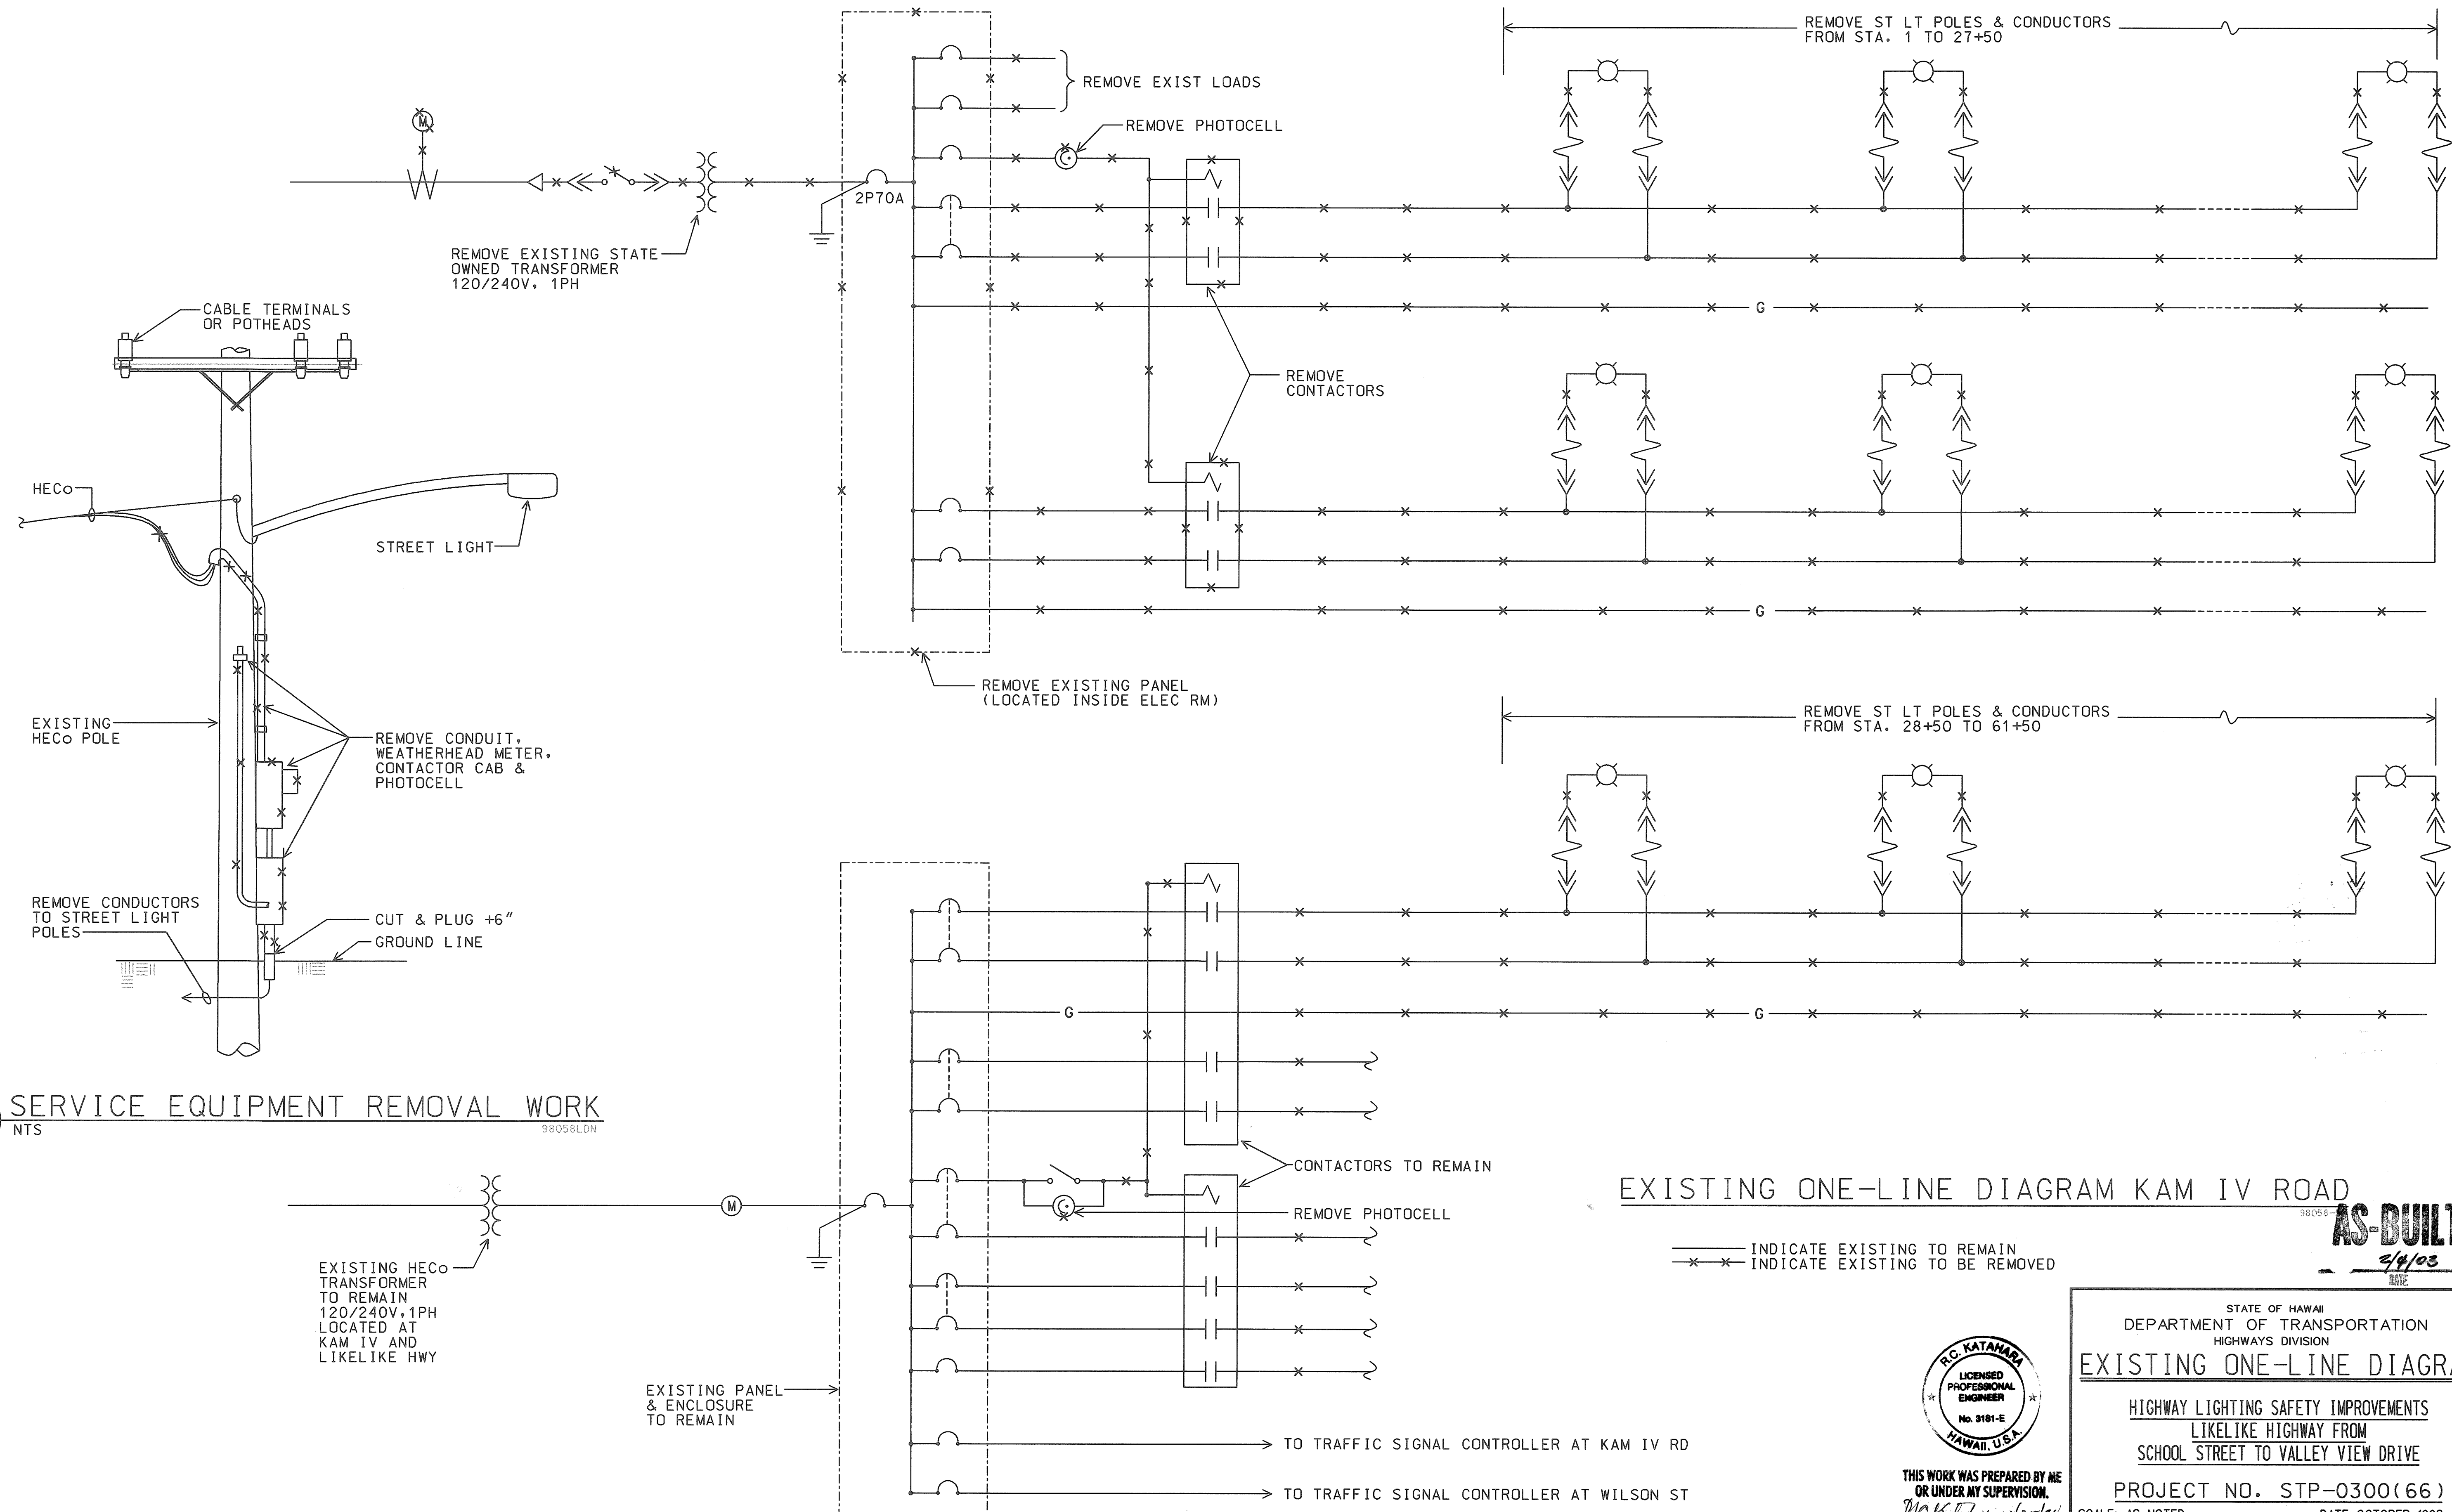


A
E21 NTS

SERVICE EQUIPMENT REMOVAL WORK

98058LDN

EXISTING ONE-LINE DIAGRAM KAM IV ROAD

AS-BUILT
2/4/03
DATE

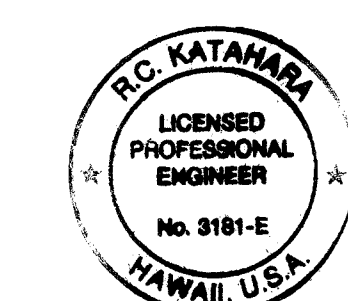

THIS WORK WAS PREPARED BY ME
OR UNDER MY SUPERVISION.
R.C. KATAMARA 11/25/98
MK ENGINEERS, LTD.

STATE OF HAWAII
DEPARTMENT OF TRANSPORTATION
HIGHWAYS DIVISION

EXISTING ONE-LINE DIAGRAM


HIGHWAY LIGHTING SAFETY IMPROVEMENTS
LIKELIKE HIGHWAY FROM
SCHOOL STREET TO VALLEY VIEW DRIVE

PROJECT NO. STP-0300(66)


SCALE: AS NOTED DATE: OCTOBER 1998

SHEET No. E21 OF 56 SHEETS


FED. ROAD DIST. NO.	STATE	FED. AID PROJ. NO.	FISCAL YEAR	SHEET NO.	TOTAL SHEETS
HAWAII	HAW.	STP-0300(66)	1998		

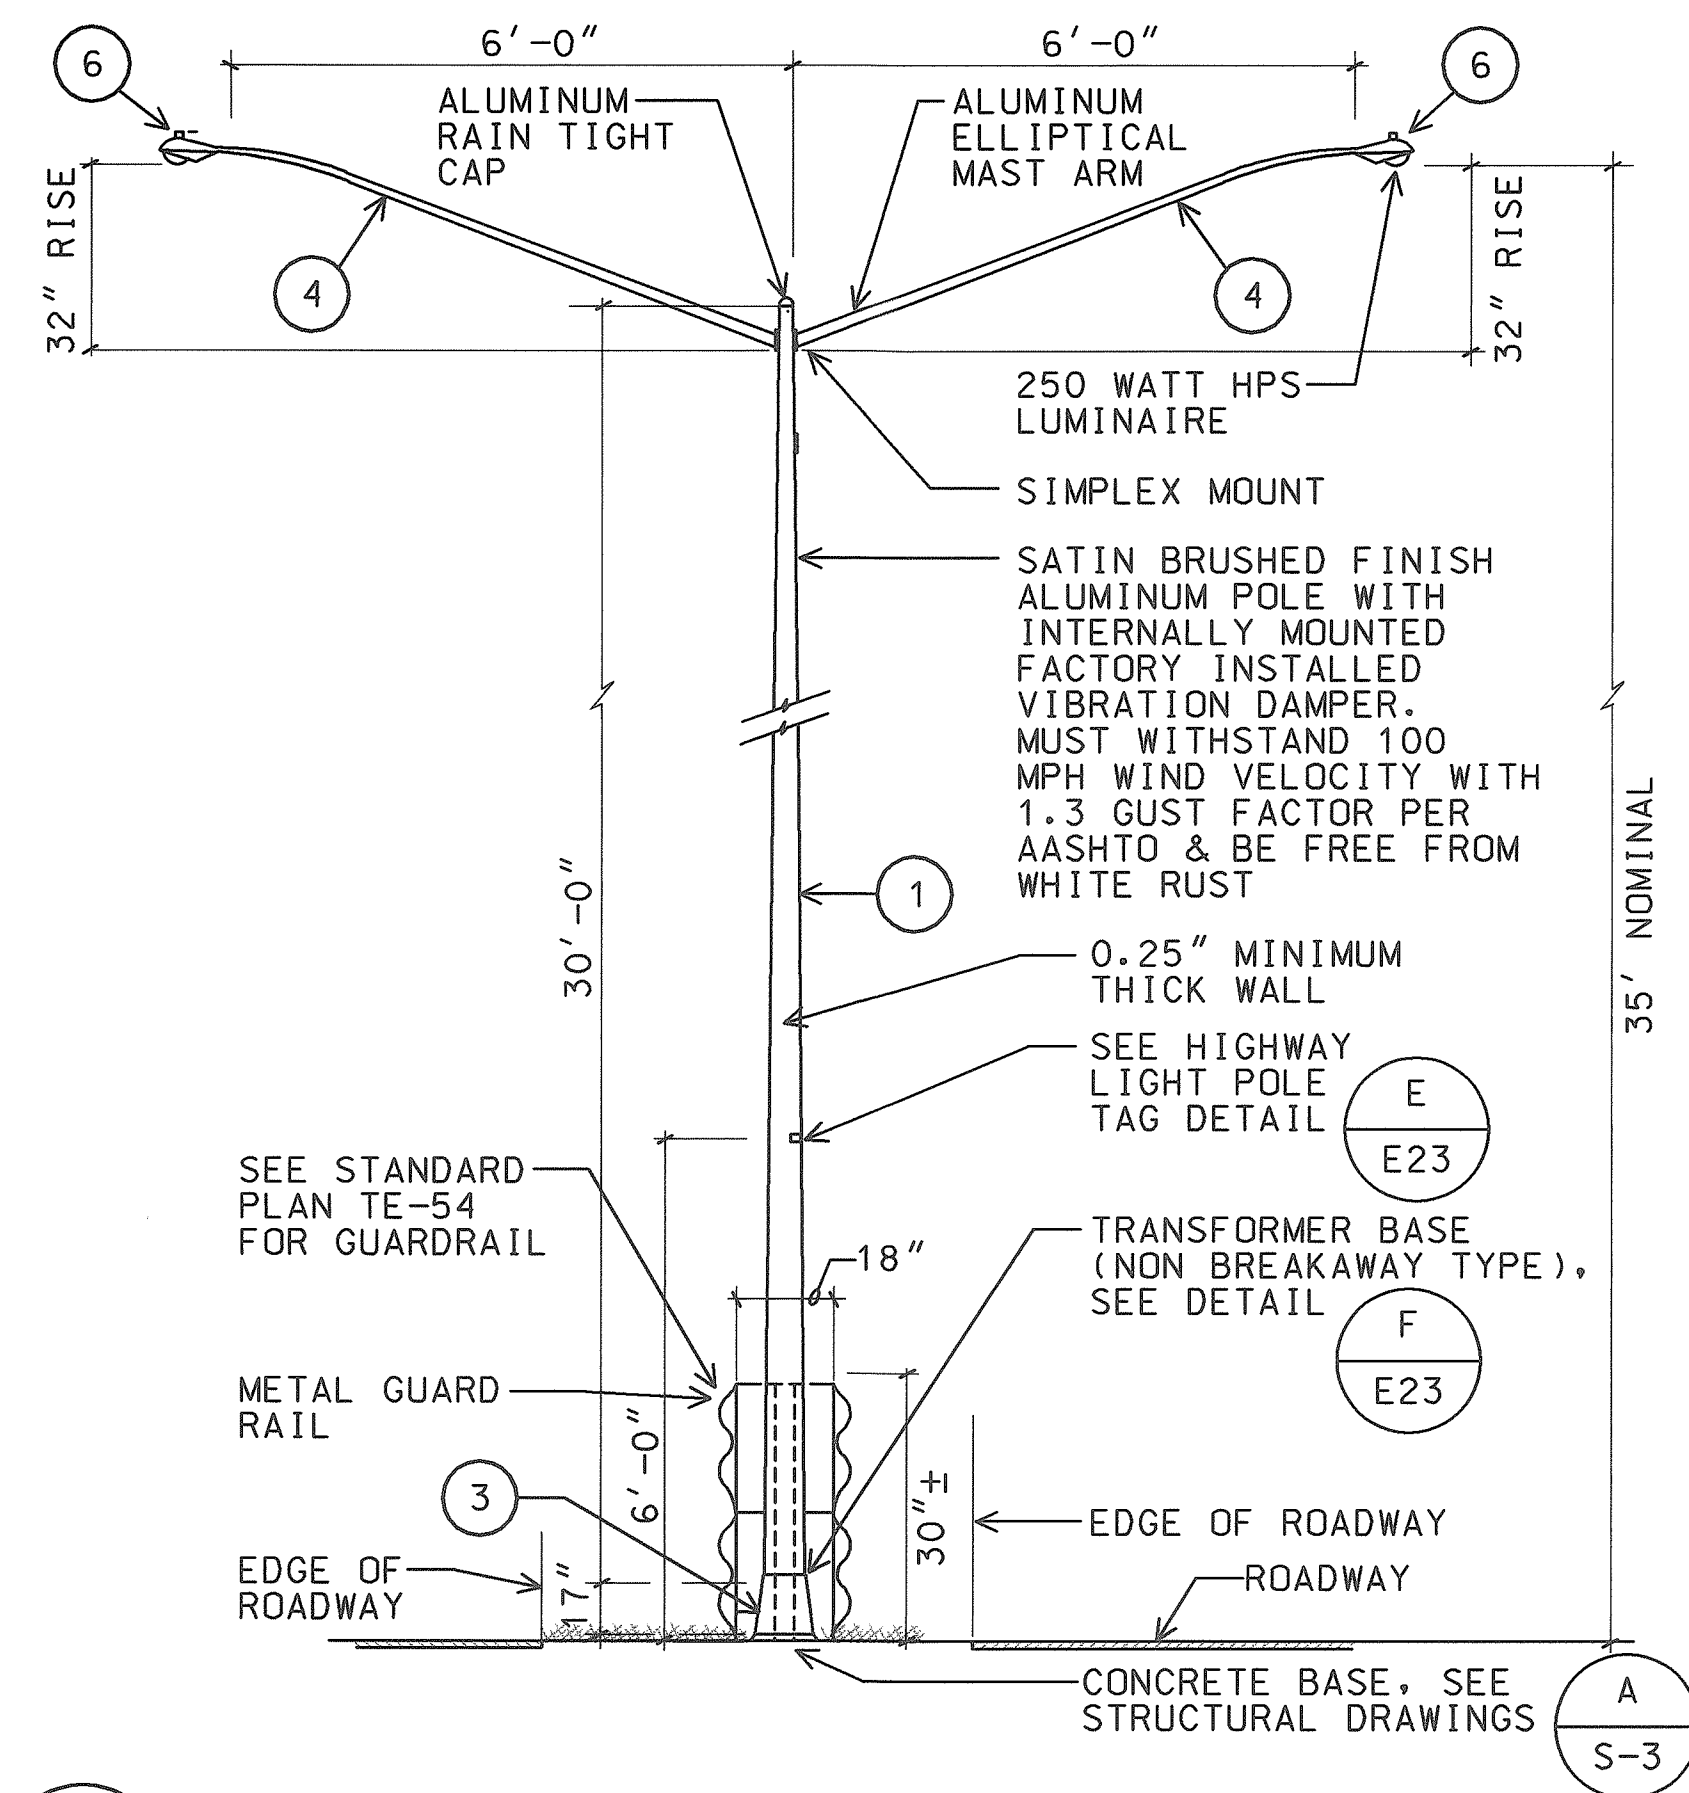

A STREET LIGHT STANDARD INSTALLATION BASE
E23 NTS 98058LDF

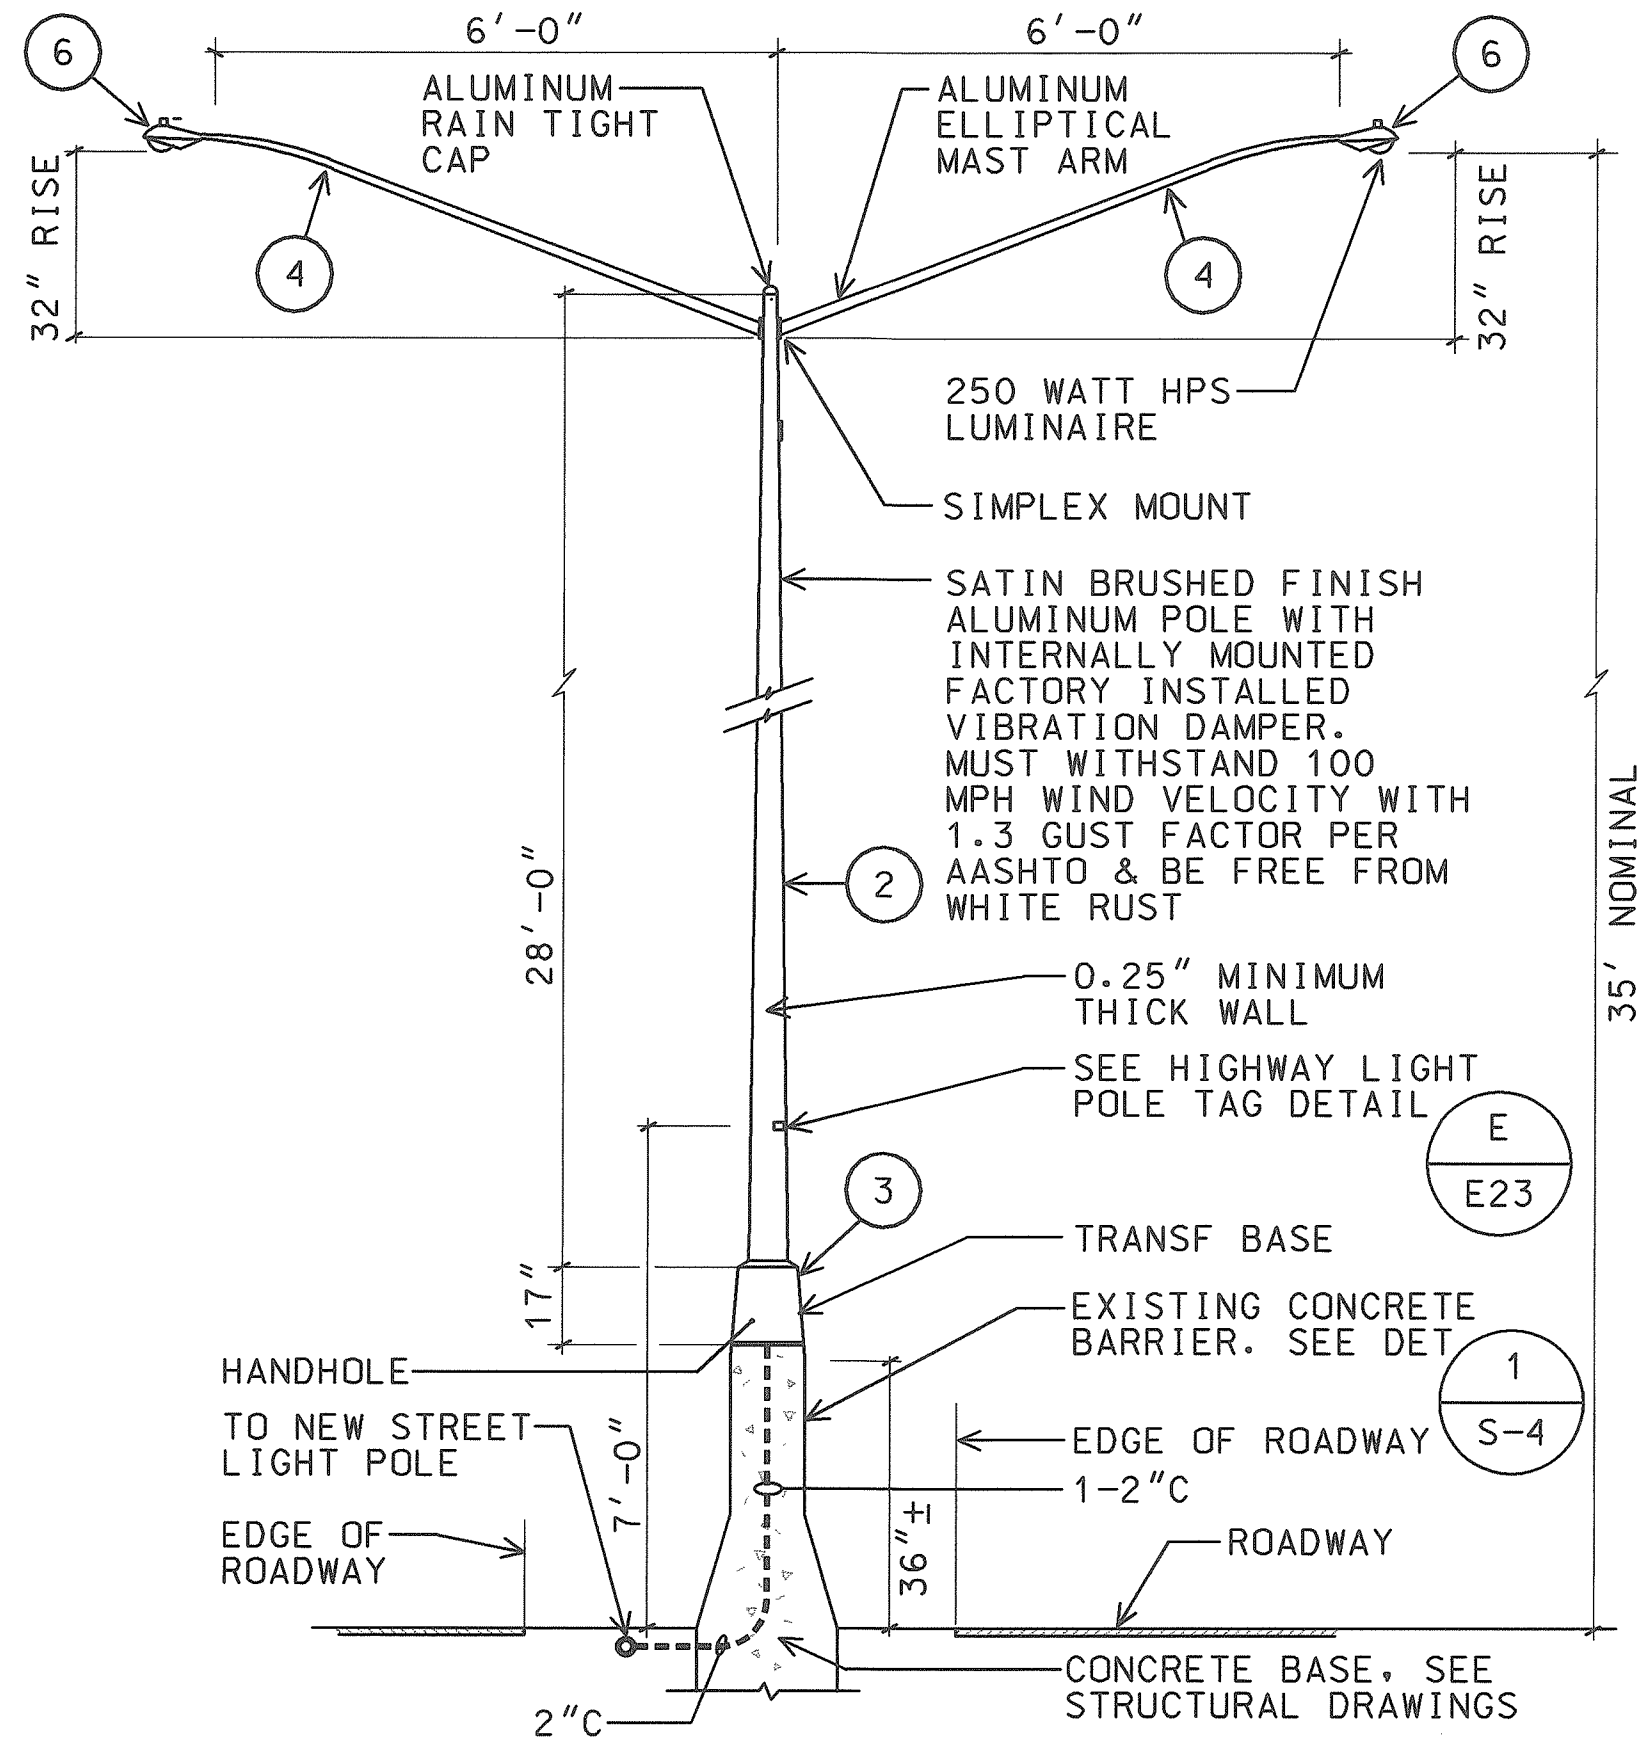


B STREET LIGHT STANDARD INSTALLATION BASE
E23 NTS 98058LDG


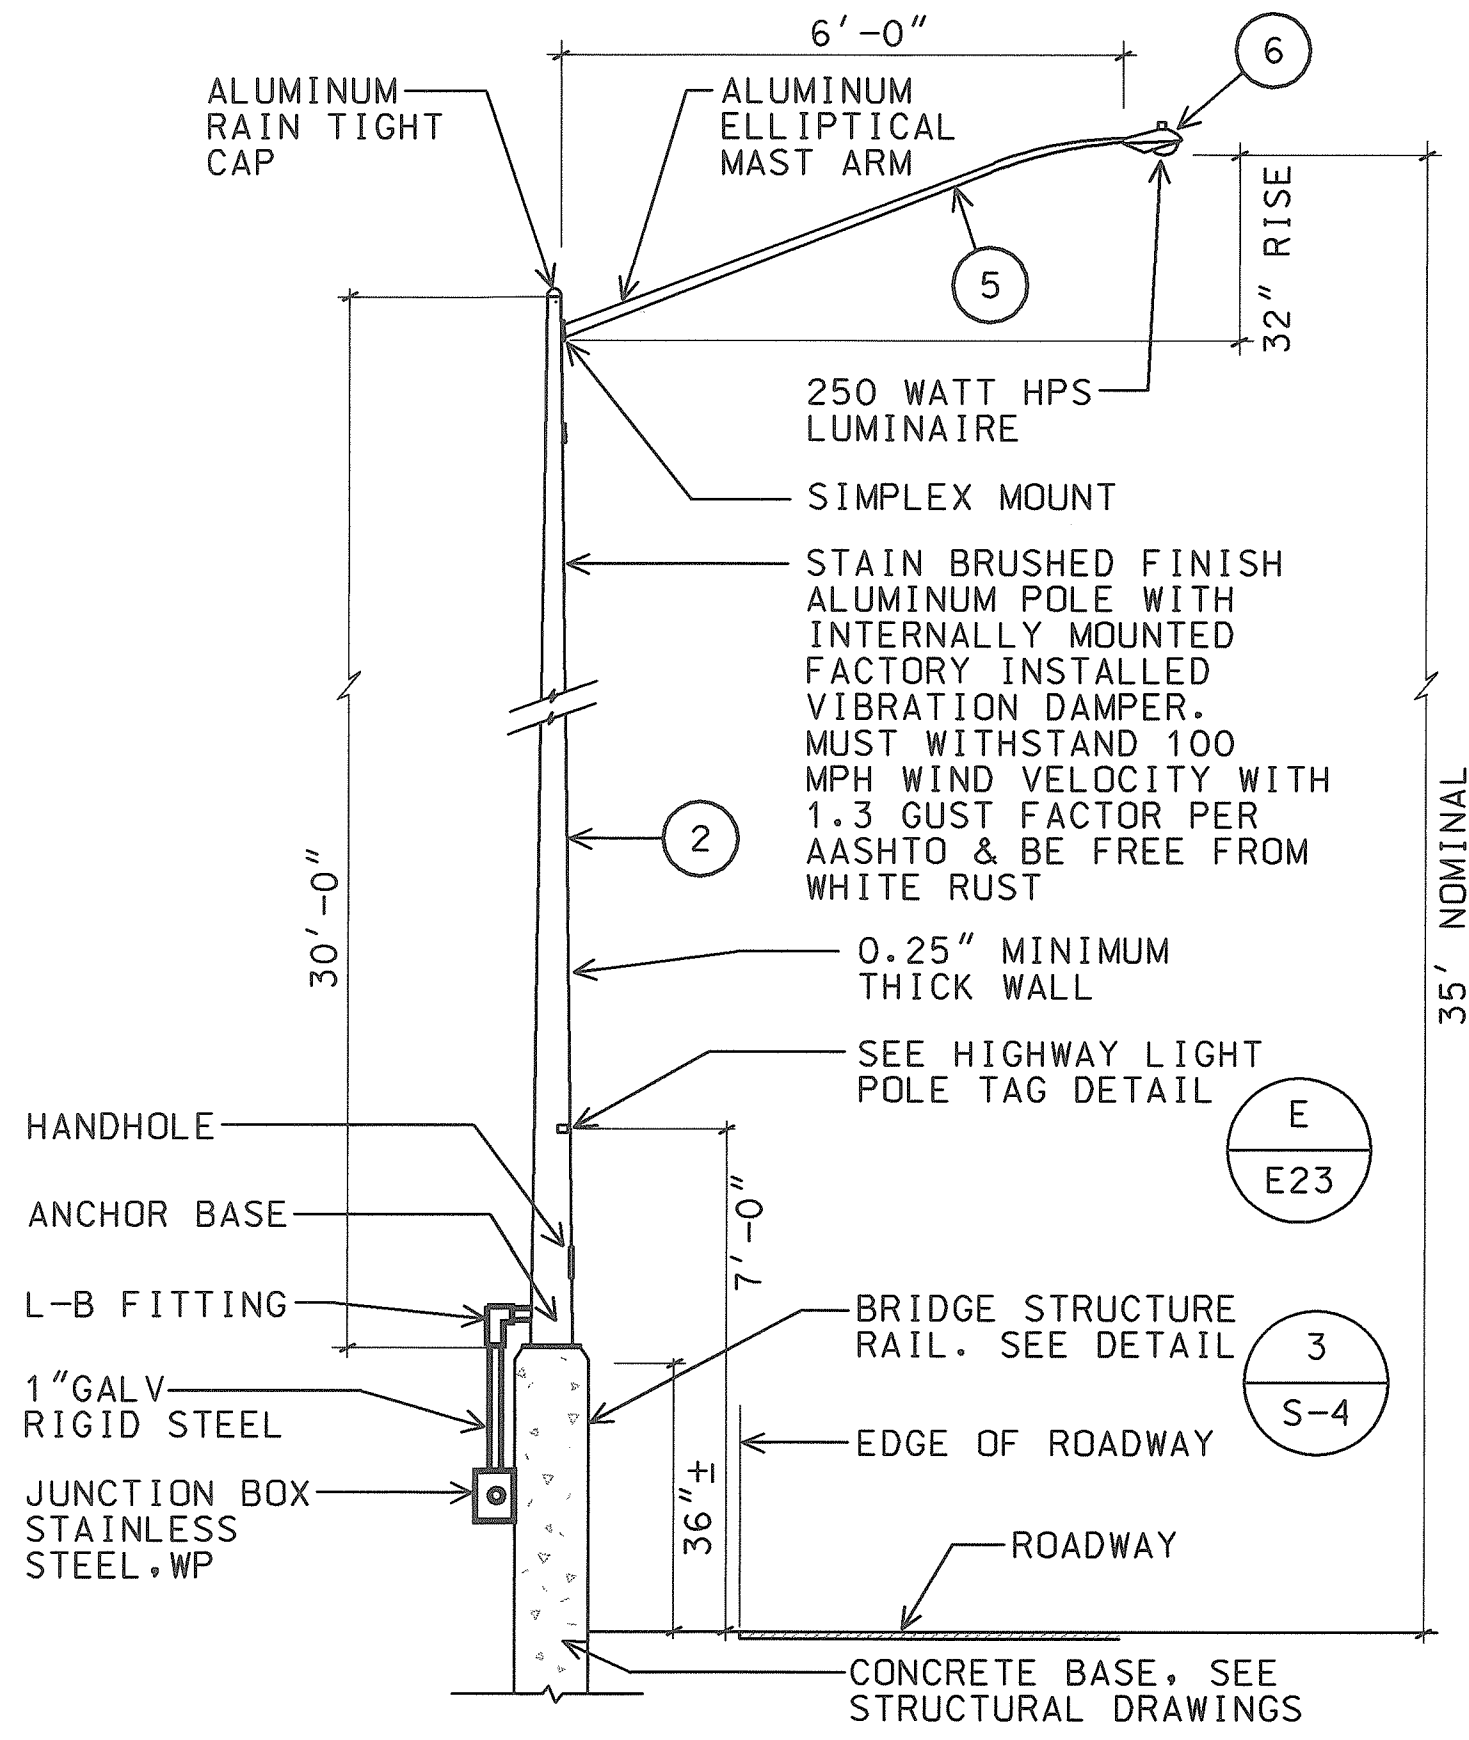


C STREET LIGHT STANDARD INSTALLATION BASE
E23 NTS 98058LDH

D STREET LIGHT STANDARD INSTALLATION BASE
E23 NTS 98058LDI

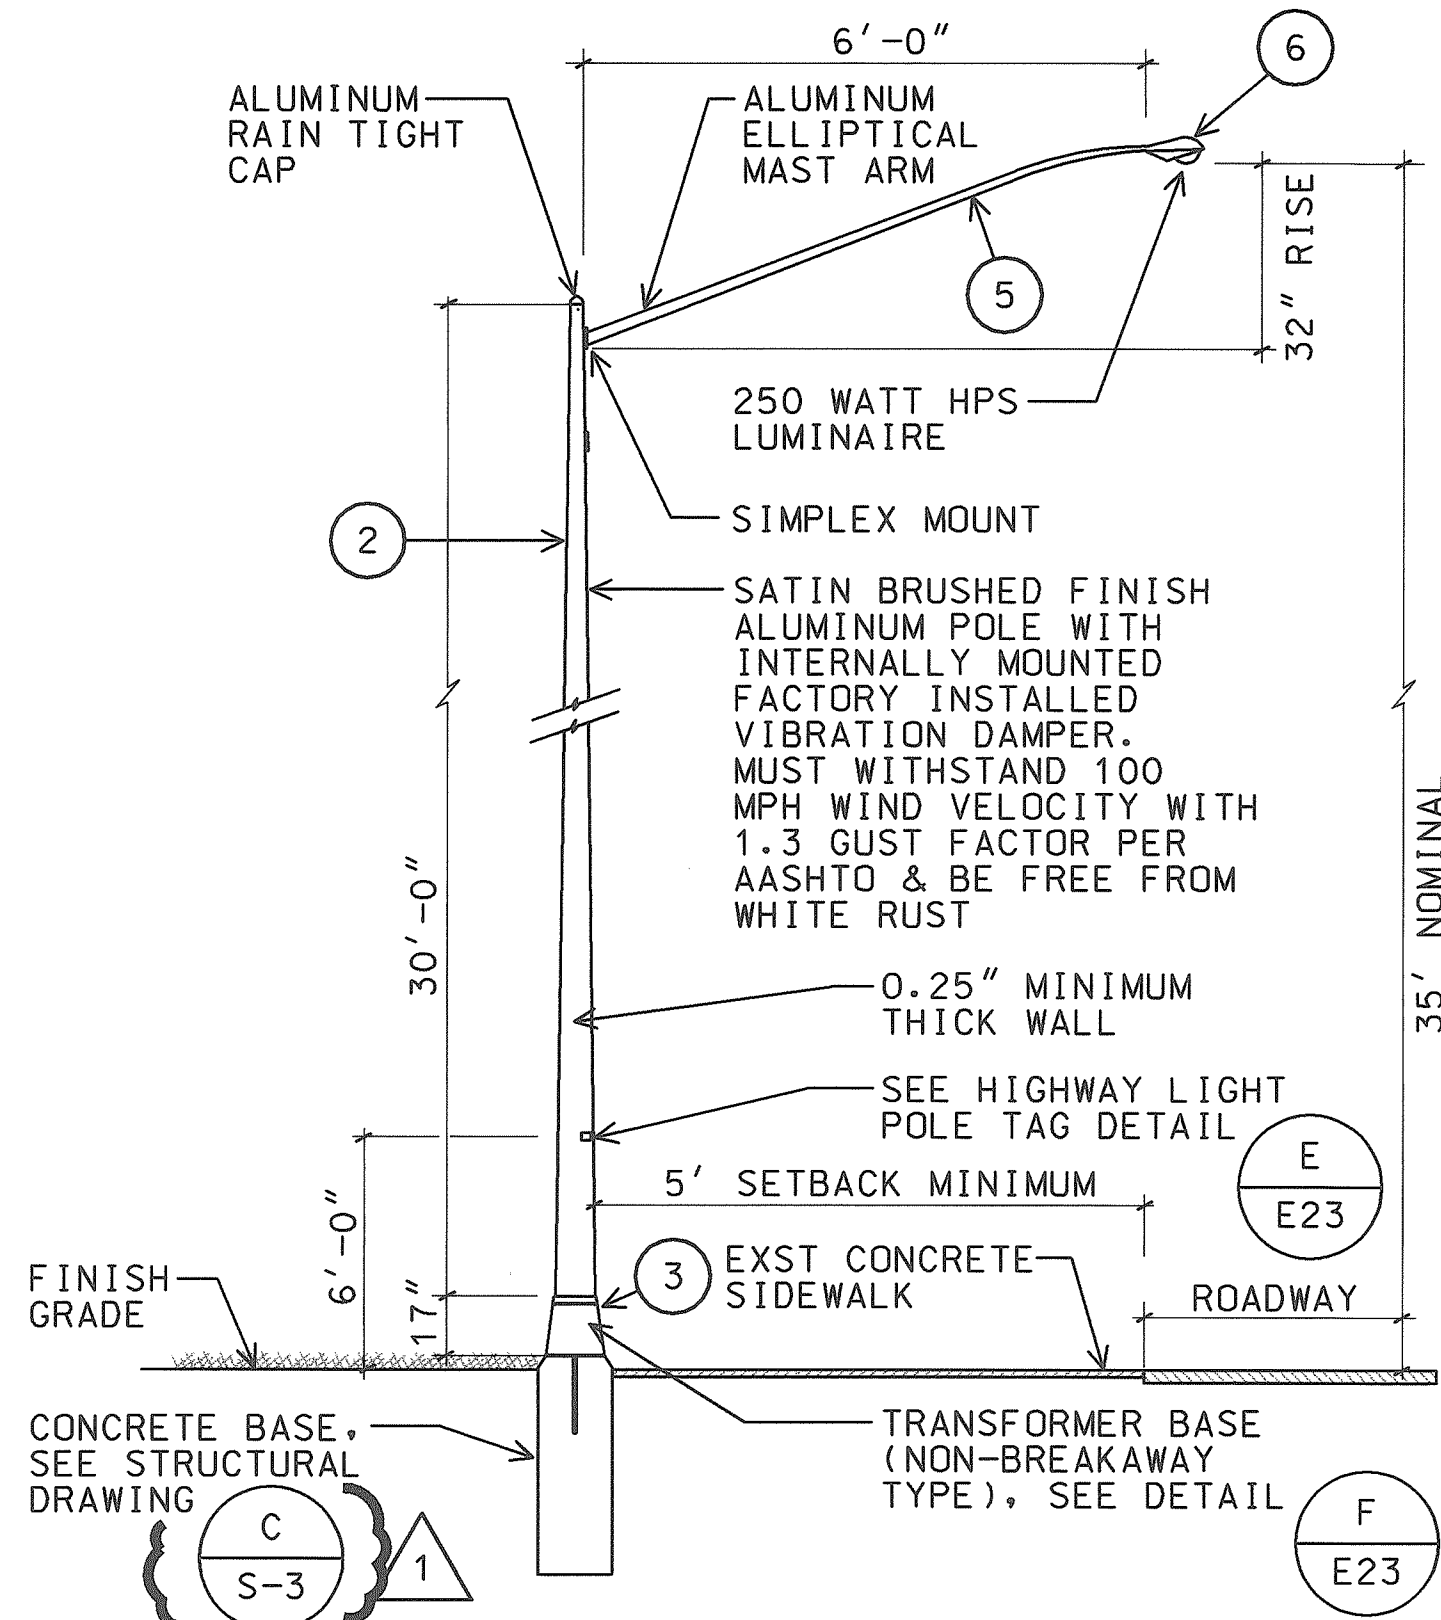

E TYPICAL TRANSFORMER BASE WIRING DETAIL
E23 NTS 98058LDJ

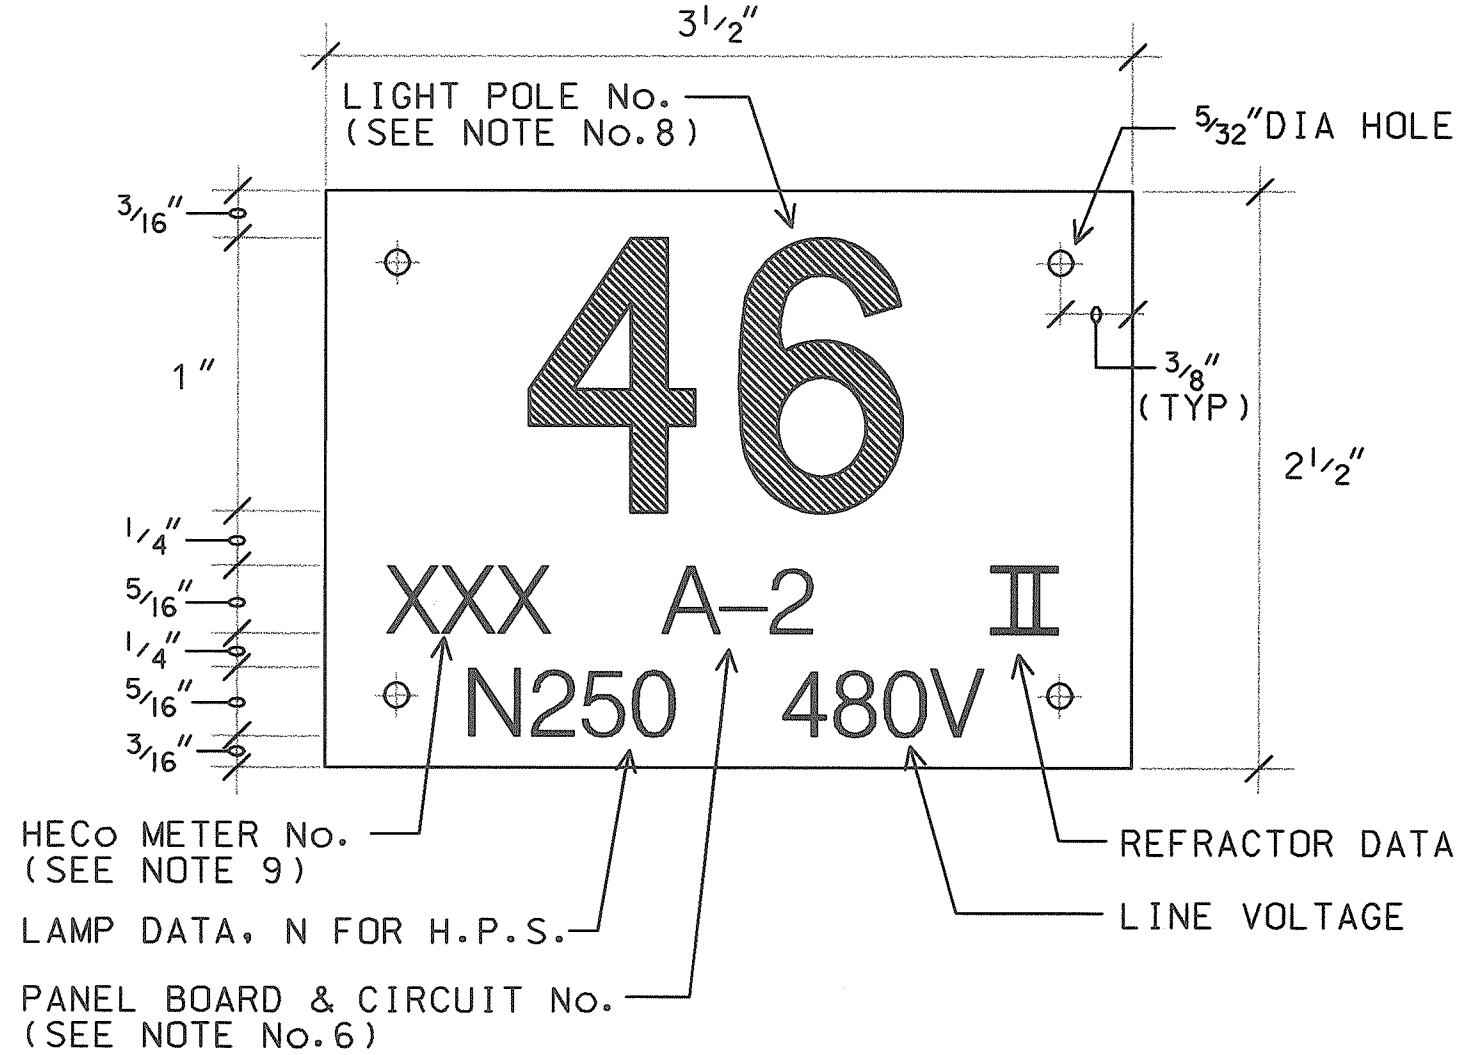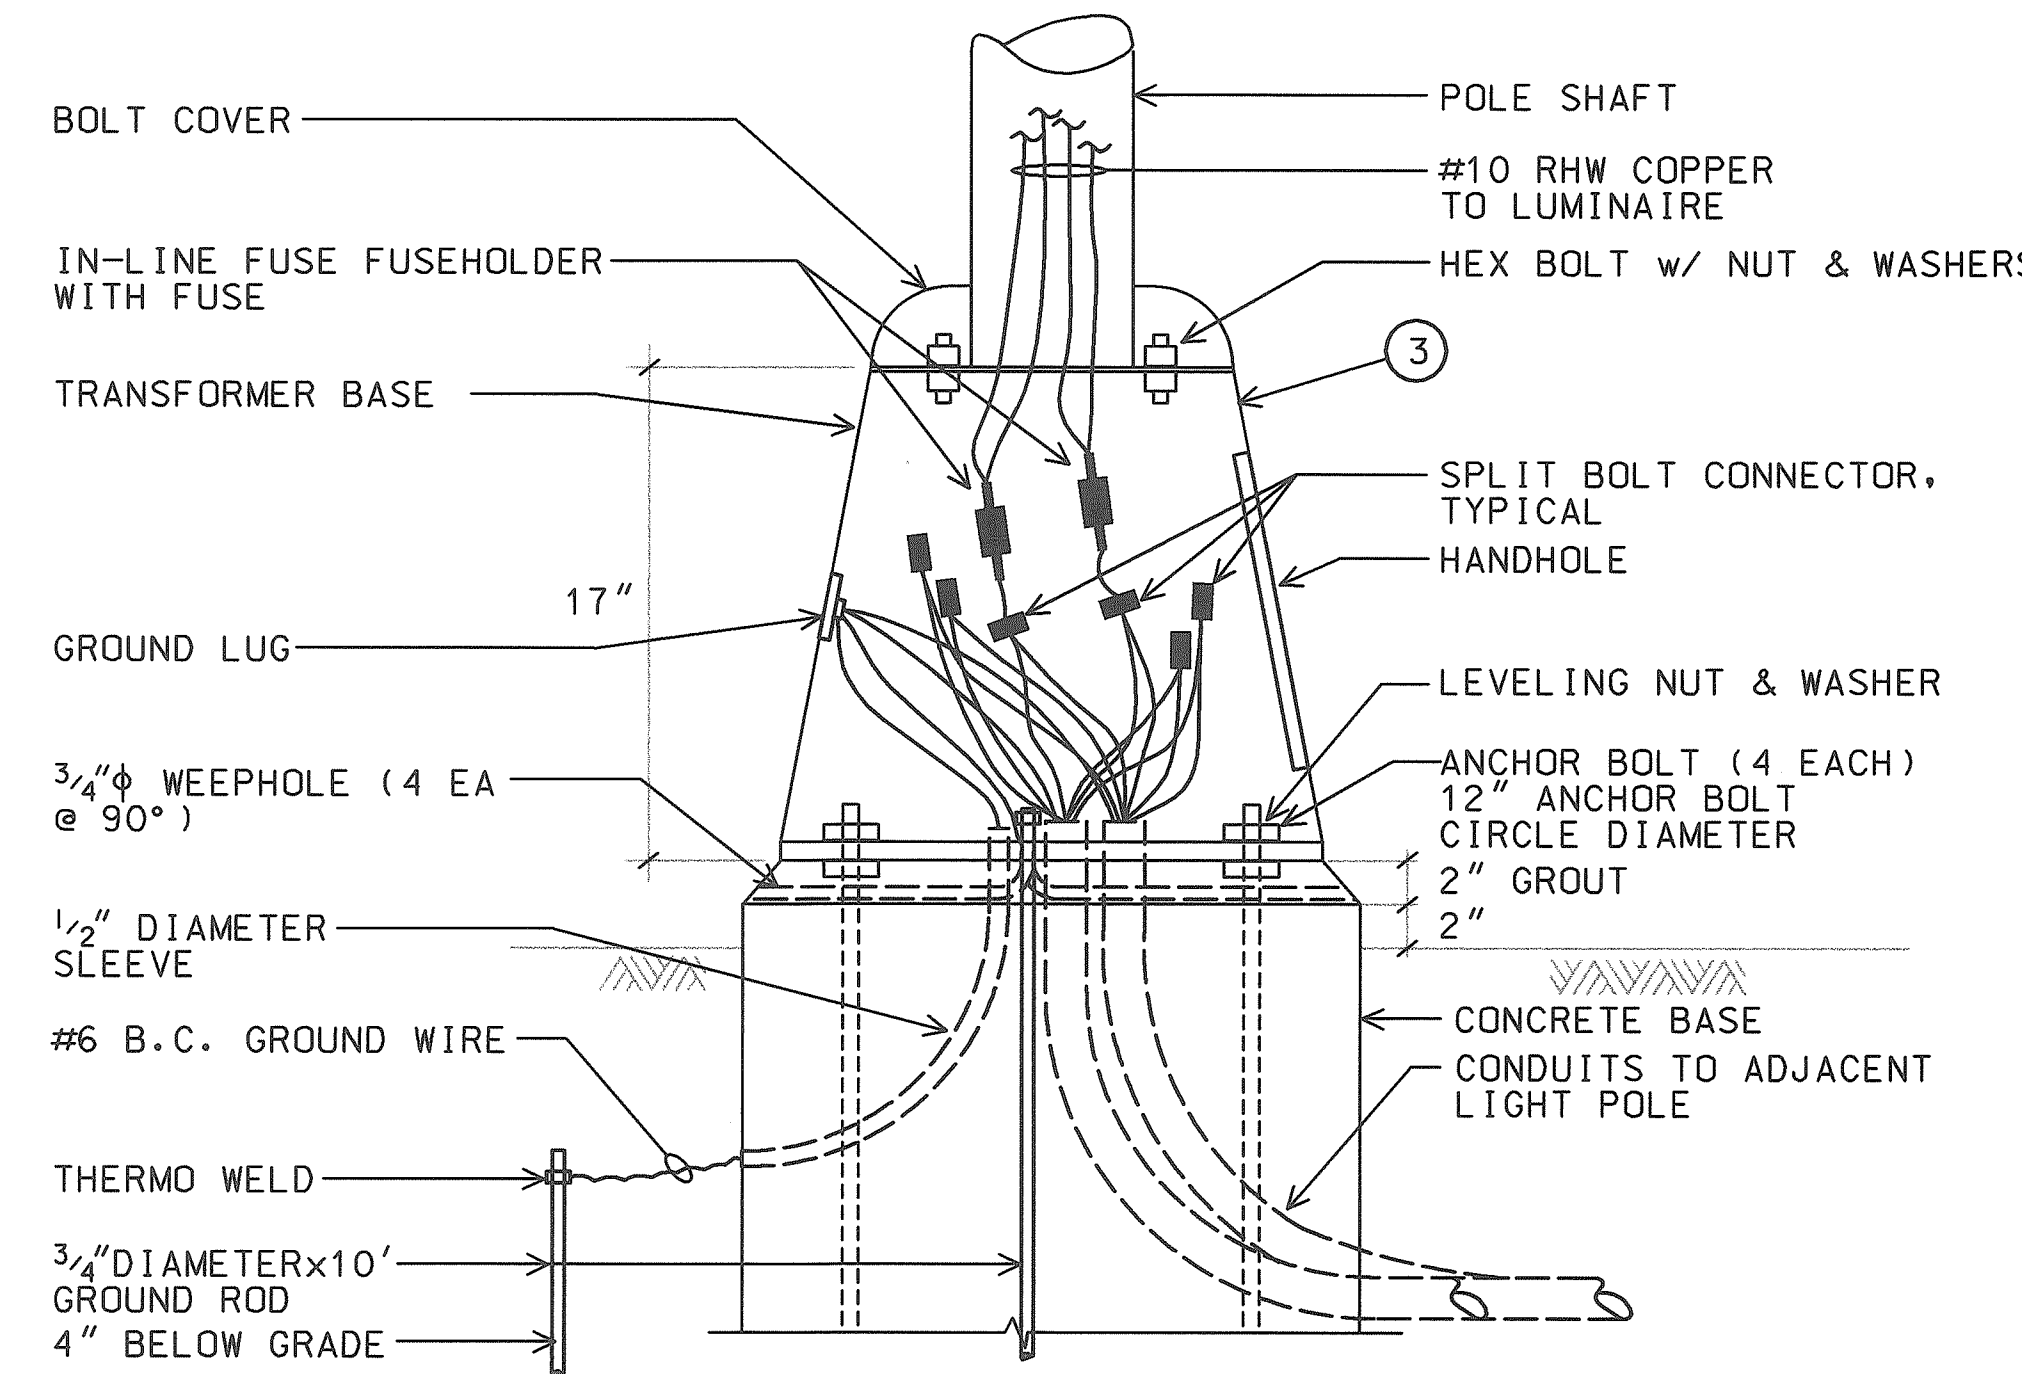




F HIGHWAY LIGHT POLE TAG DETAIL
E23 NTS 98058LDK

MATERIAL LIST		
ITEM	DESCRIPTION	MANUFACTURER
1	LIGHT POLE, 28', ALUM	LEXINGTON 2708-45808T4
2	LIGHT POLE, 30', ALUM	LEXINGTON 2908-45808T4
3	TRANSFORMER BASE (ALUM) NON-BREAKAWAY TYPE	LEXINGTON 08R1012S17
4	MAST ARM, 6', ALUM, DOUBLE SIMPLEX MOUNT	LEXINGTON 2MA0632S
5	MAST ARM, 6', ALUM, SINGLE SIMPLEX MOUNT	LEXINGTON 1MA0632S
6	LUMINAIRE, 250W HPS	GENERAL ELECTRIC M4RR-25-S-5-M-1-G-MS2

- NOTES:**
- USE 3 PLY LAMINATED FLEXIBLE PLASTIC BLACK-WHITE-BLACK THICKNESS BLACK CAP SHEET-0.010", WHITE BASE SHEET-0.052", BLACK BASE SHEET-0.010".
 - LIGHT POLE NUMBER SIZE SHALL BE 1" HIGH AND ENGRAVED 1/8" WIDE, WHITE IN COLOR (NUMBER AS REQUIRED).
 - NOMENCLATURE SIZE SHALL BE 5/16" HIGH AND ENGRAVED 1/32" WIDE, WHITE IN COLOR (HECO VAULT NUMBER PANEL BOARD AND CIRCUIT NUMBER, LINE VOLTAGE, LAMP DATA AND REFRACTOR DATA AS REQUIRED).
 - ATTACH TO ALUMINUM AND STEEL POST WITH NO. 8 STAINLESS STEEL, 1/2" LONG DRIVE SCREWS IN 1/8" DRILL HOLE. ATTACH TO WOOD POLES WITH 4D ALUMINUM NAIL.
 - NUMBERS ARE INSCRIBED BY CUTTING THROUGH "BLACK CAP SHEET" TO EXPOSE "WHITE LETTERS."
 - NOMENCLATURE REQUIRED FOR SYSTEMS WITH TWO OR MORE CIRCUITS (LETTER INDICATES PANEL BOARD, NUMBER INDICATES CIRCUIT).
 - FOR LIGHT POLES INSTALLED ON RAMP, ASSIGN NUMBERS TO INCLUDE RAMP I.D. AND LIGHT NUMBER. LEGEND MAY BE LESS THAN ONE (1) INCH IN HEIGHT.
 - LIGHT NUMBERS SHALL BE OBTAINED FROM THE STATE. USE AN ALPHABET SUFFIX TO DESIGNATE LIGHTS MOUNTED ON THE SAME POLE (e.g. 123A & 123B).
 - FOR NON-METERED SYSTEM, LEAVE THIS BLOCK BLANK.





8/16/99	REVISED DETAIL	STATE OF HAWAII DEPARTMENT OF TRANSPORTATION HIGHWAYS DIVISION
DATE	REV	DESCRIPTION
STREET LIGHT DETAILS		
HIGHWAY LIGHTING SAFETY IMPROVEMENTS LIKELIKE HIGHWAY FROM SCHOOL STREET TO VALLEY VIEW DRIVE		
PROJECT NO. STP-0300(66)		
SCALE: AS NOTED DATE: OCTOBER 1998		
SHEET No. E23 OF 56 SHEETS		

FED. ROAD DIST. NO.	STATE	FED. AID PROJ. NO.	FISCAL YEAR	SHEET NO.	TOTAL SHEETS
HAWAII	HAW.	STP-0300(66)	1998		

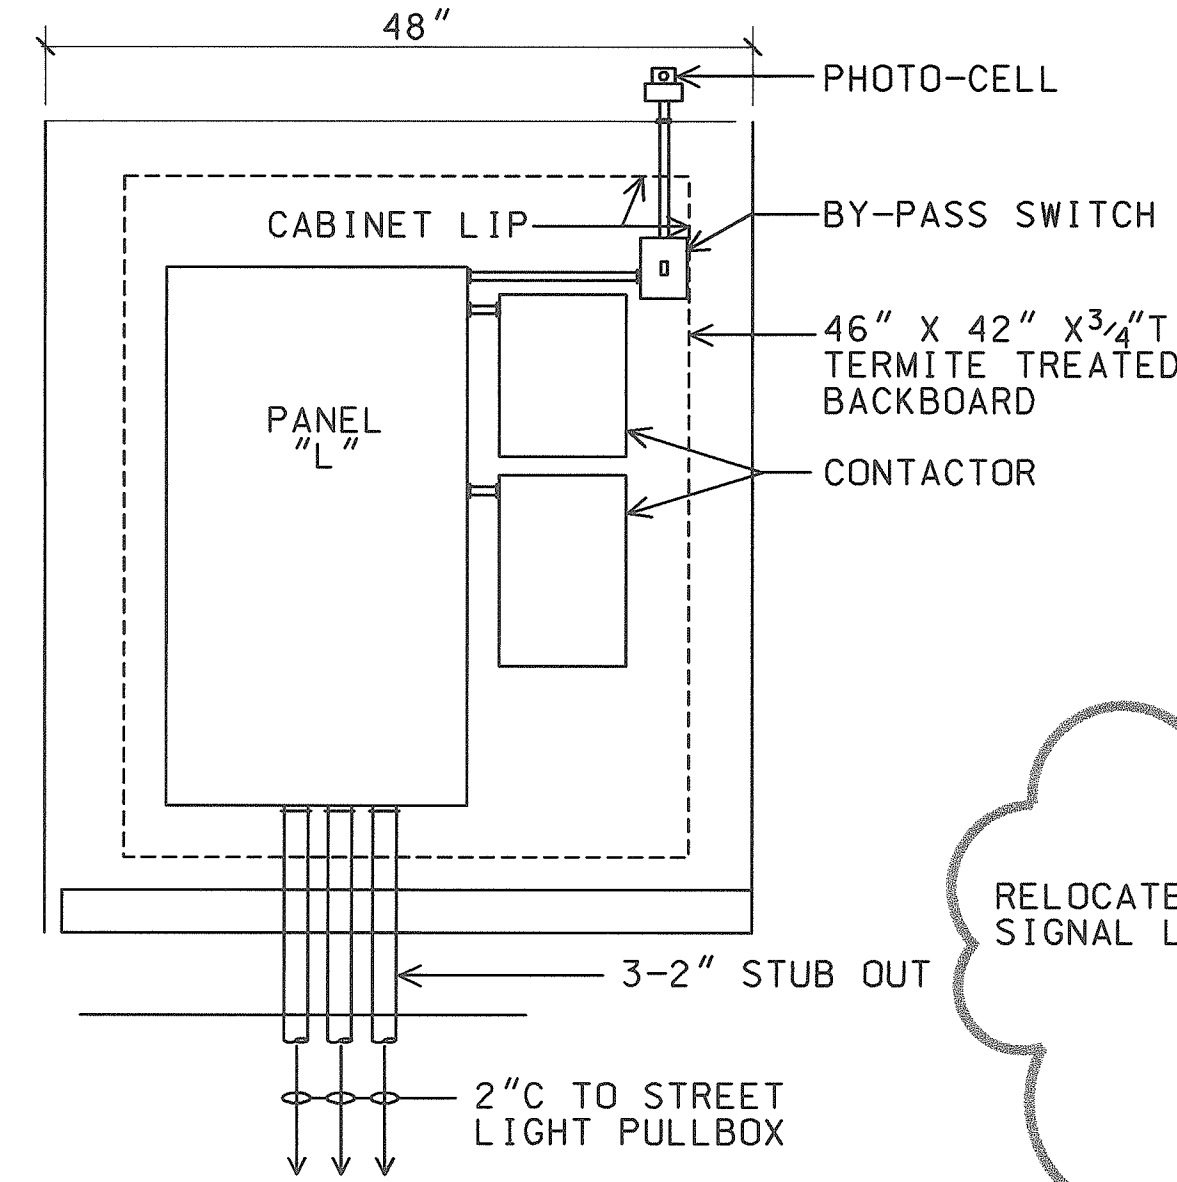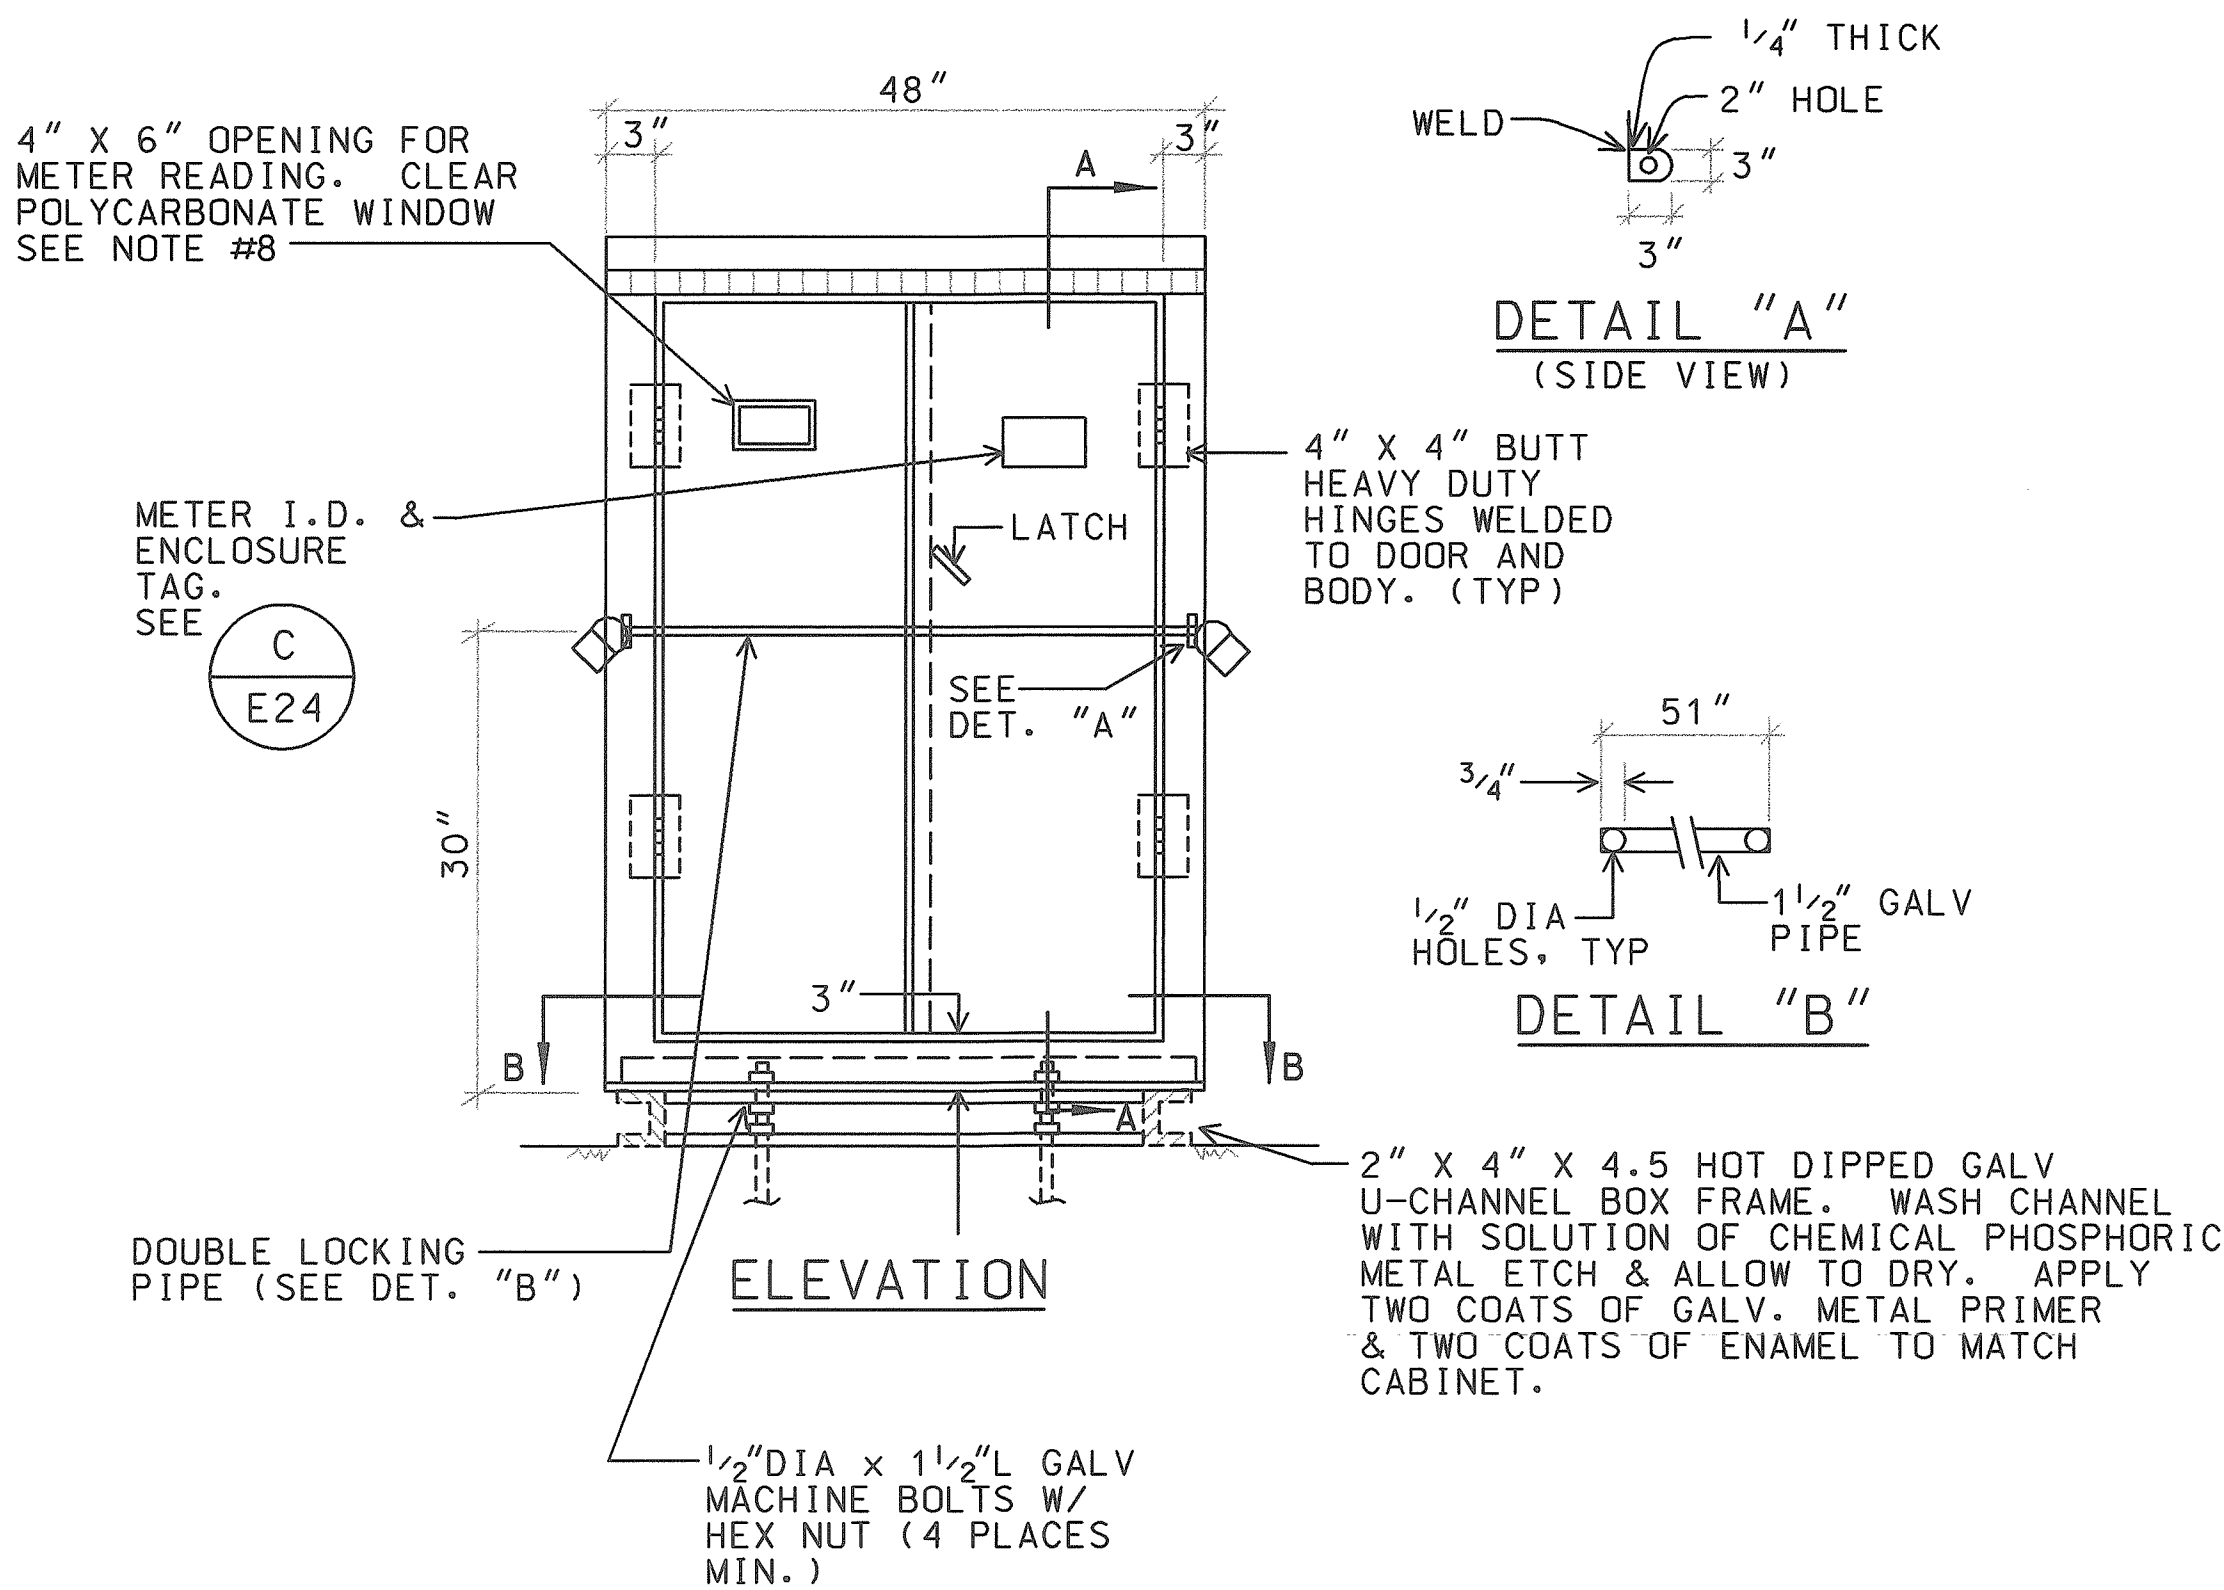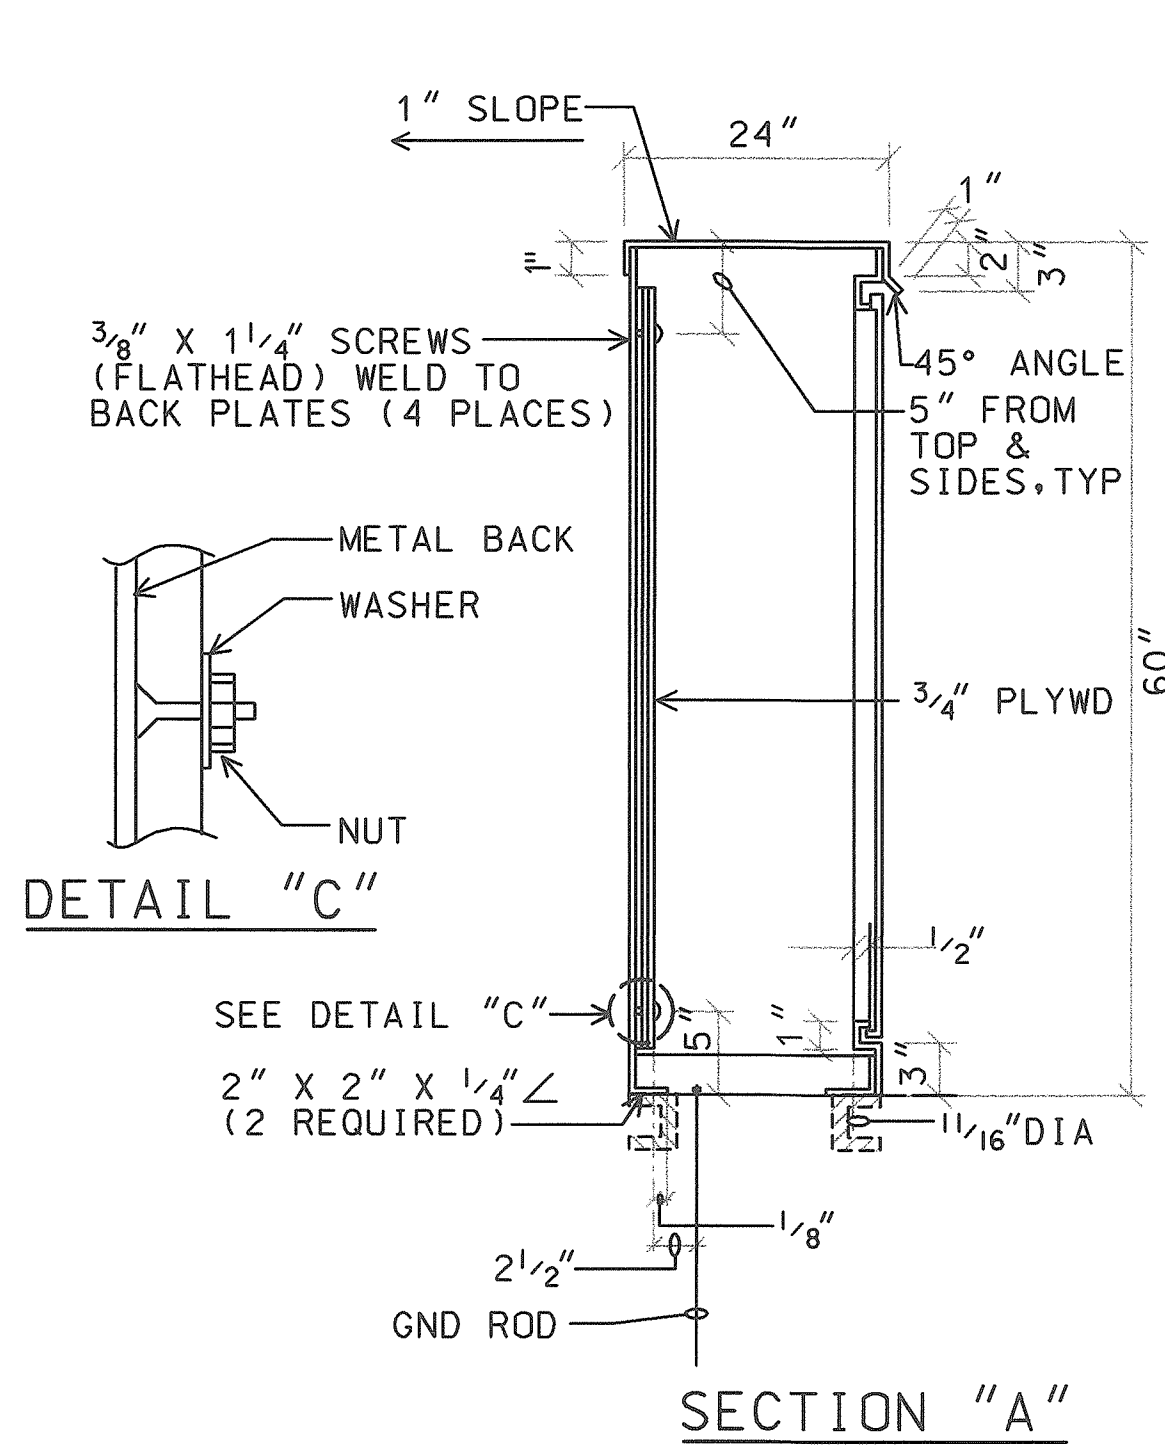


NOTES:

1. CABINET TO BE PRIMED WITH ONE COAT SHOP PRIMER.
2. PLYWOOD TO BE 3/4" THICK (MIN.) TREATED (WOLMANIZED) PLYWOOD. (EXTERIOR GRADE)
3. MADE FROM 10 ALUMINUM.
4. PROVIDE ACRYLIC ENAMEL FINISH, COLOR TO MATCH TRANSFORMER. (2 COATS)
5. ENCLOSURE SHALL BE NEMA 3R WITH NEOPRENE GASKETING.
6. PADLOCKS:
 - 1-HECO FURNISHED
 - 1-CONTRACTOR FURNISHED, BRASS CORBIN SESAME COMBINATION
7. SHOP FABRICATION DRAWINGS SHALL BE SUBMITTED FOR APPROVAL.
8. LOCATION OF OPENING FOR METER READER TO CORRESPOND WITH LOCATION OF METER.

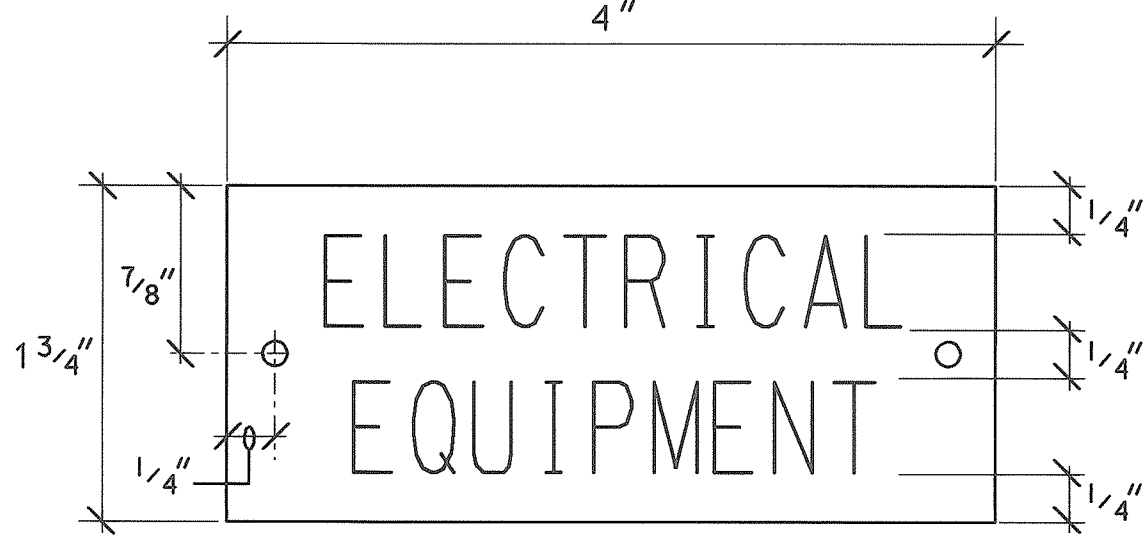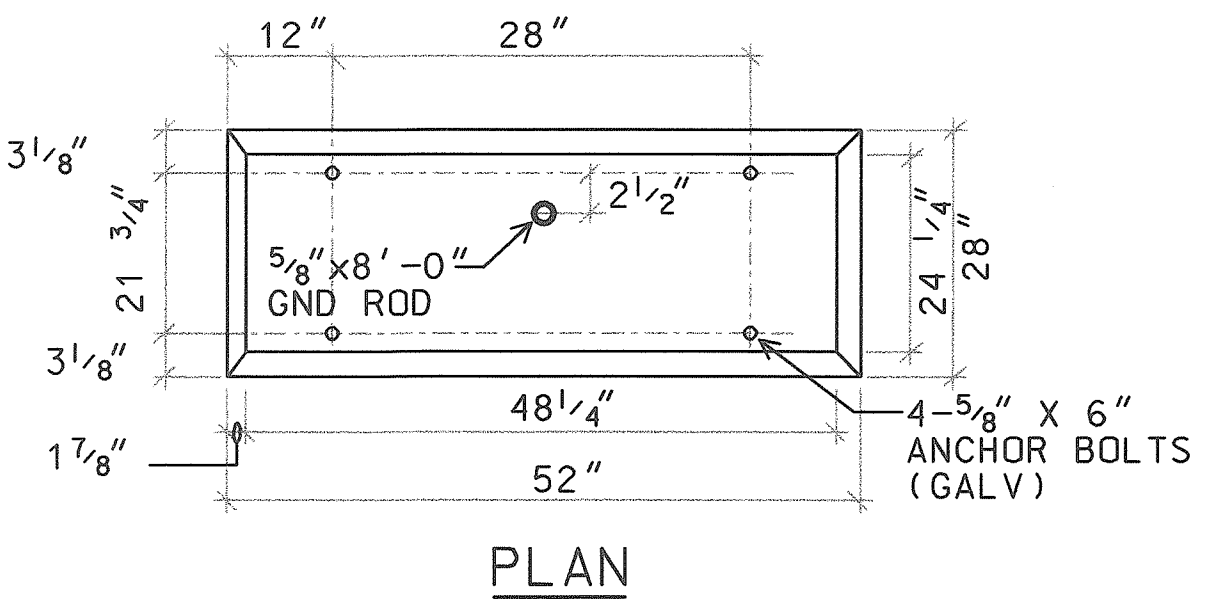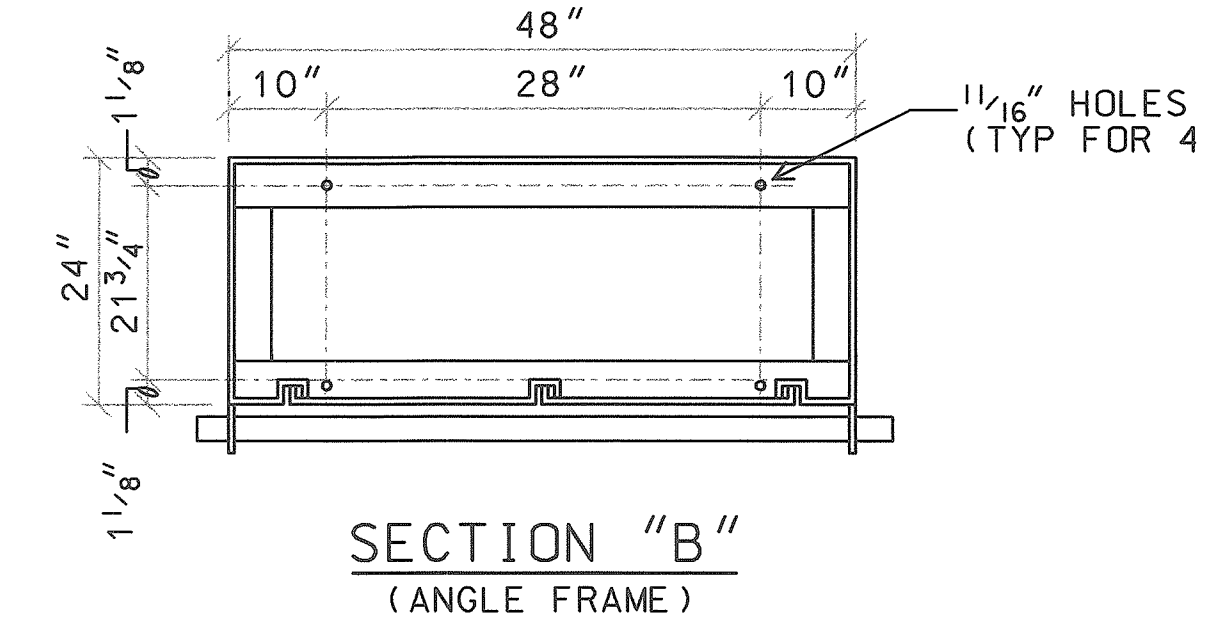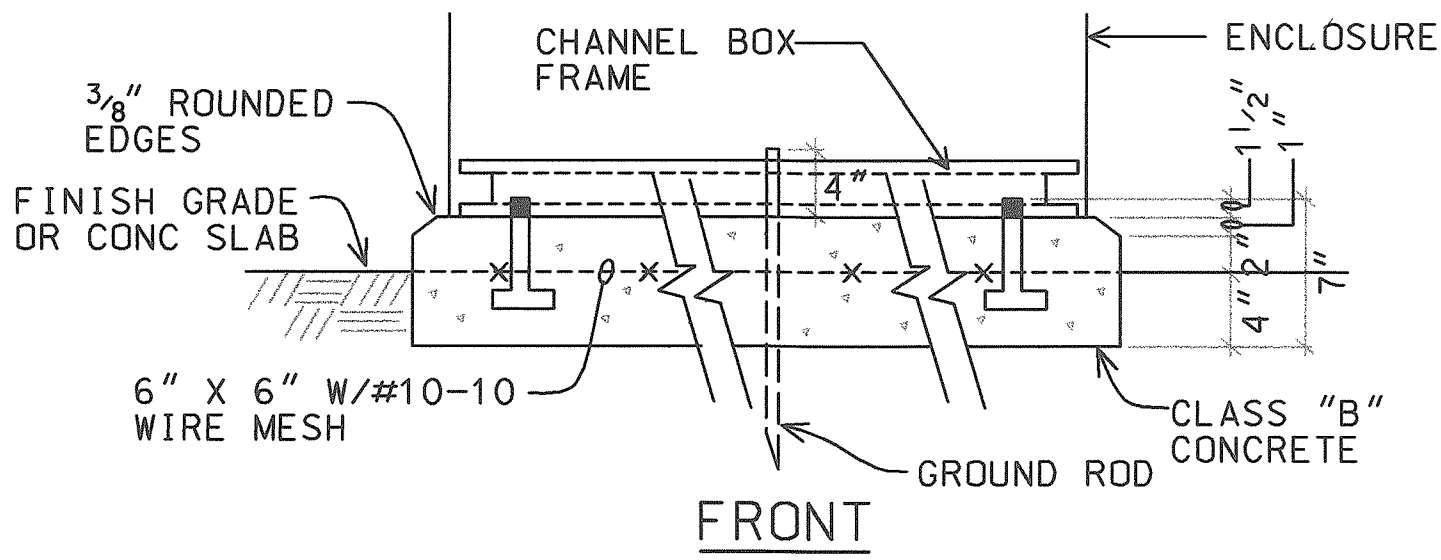

NOTES:

1. USE 2 PLY PLASTIC - BLACK, WHITE.
2. LETTER SIZE SHALL BE 1/2" HIGH AND ENGRAVED 1/16" WIDE, WHITE IN COLOR.
3. ATTACH TO EQUIPMENT ENCLOSURE WITH NO.7 STAINLESS STEEL DRIVE SCREWS.

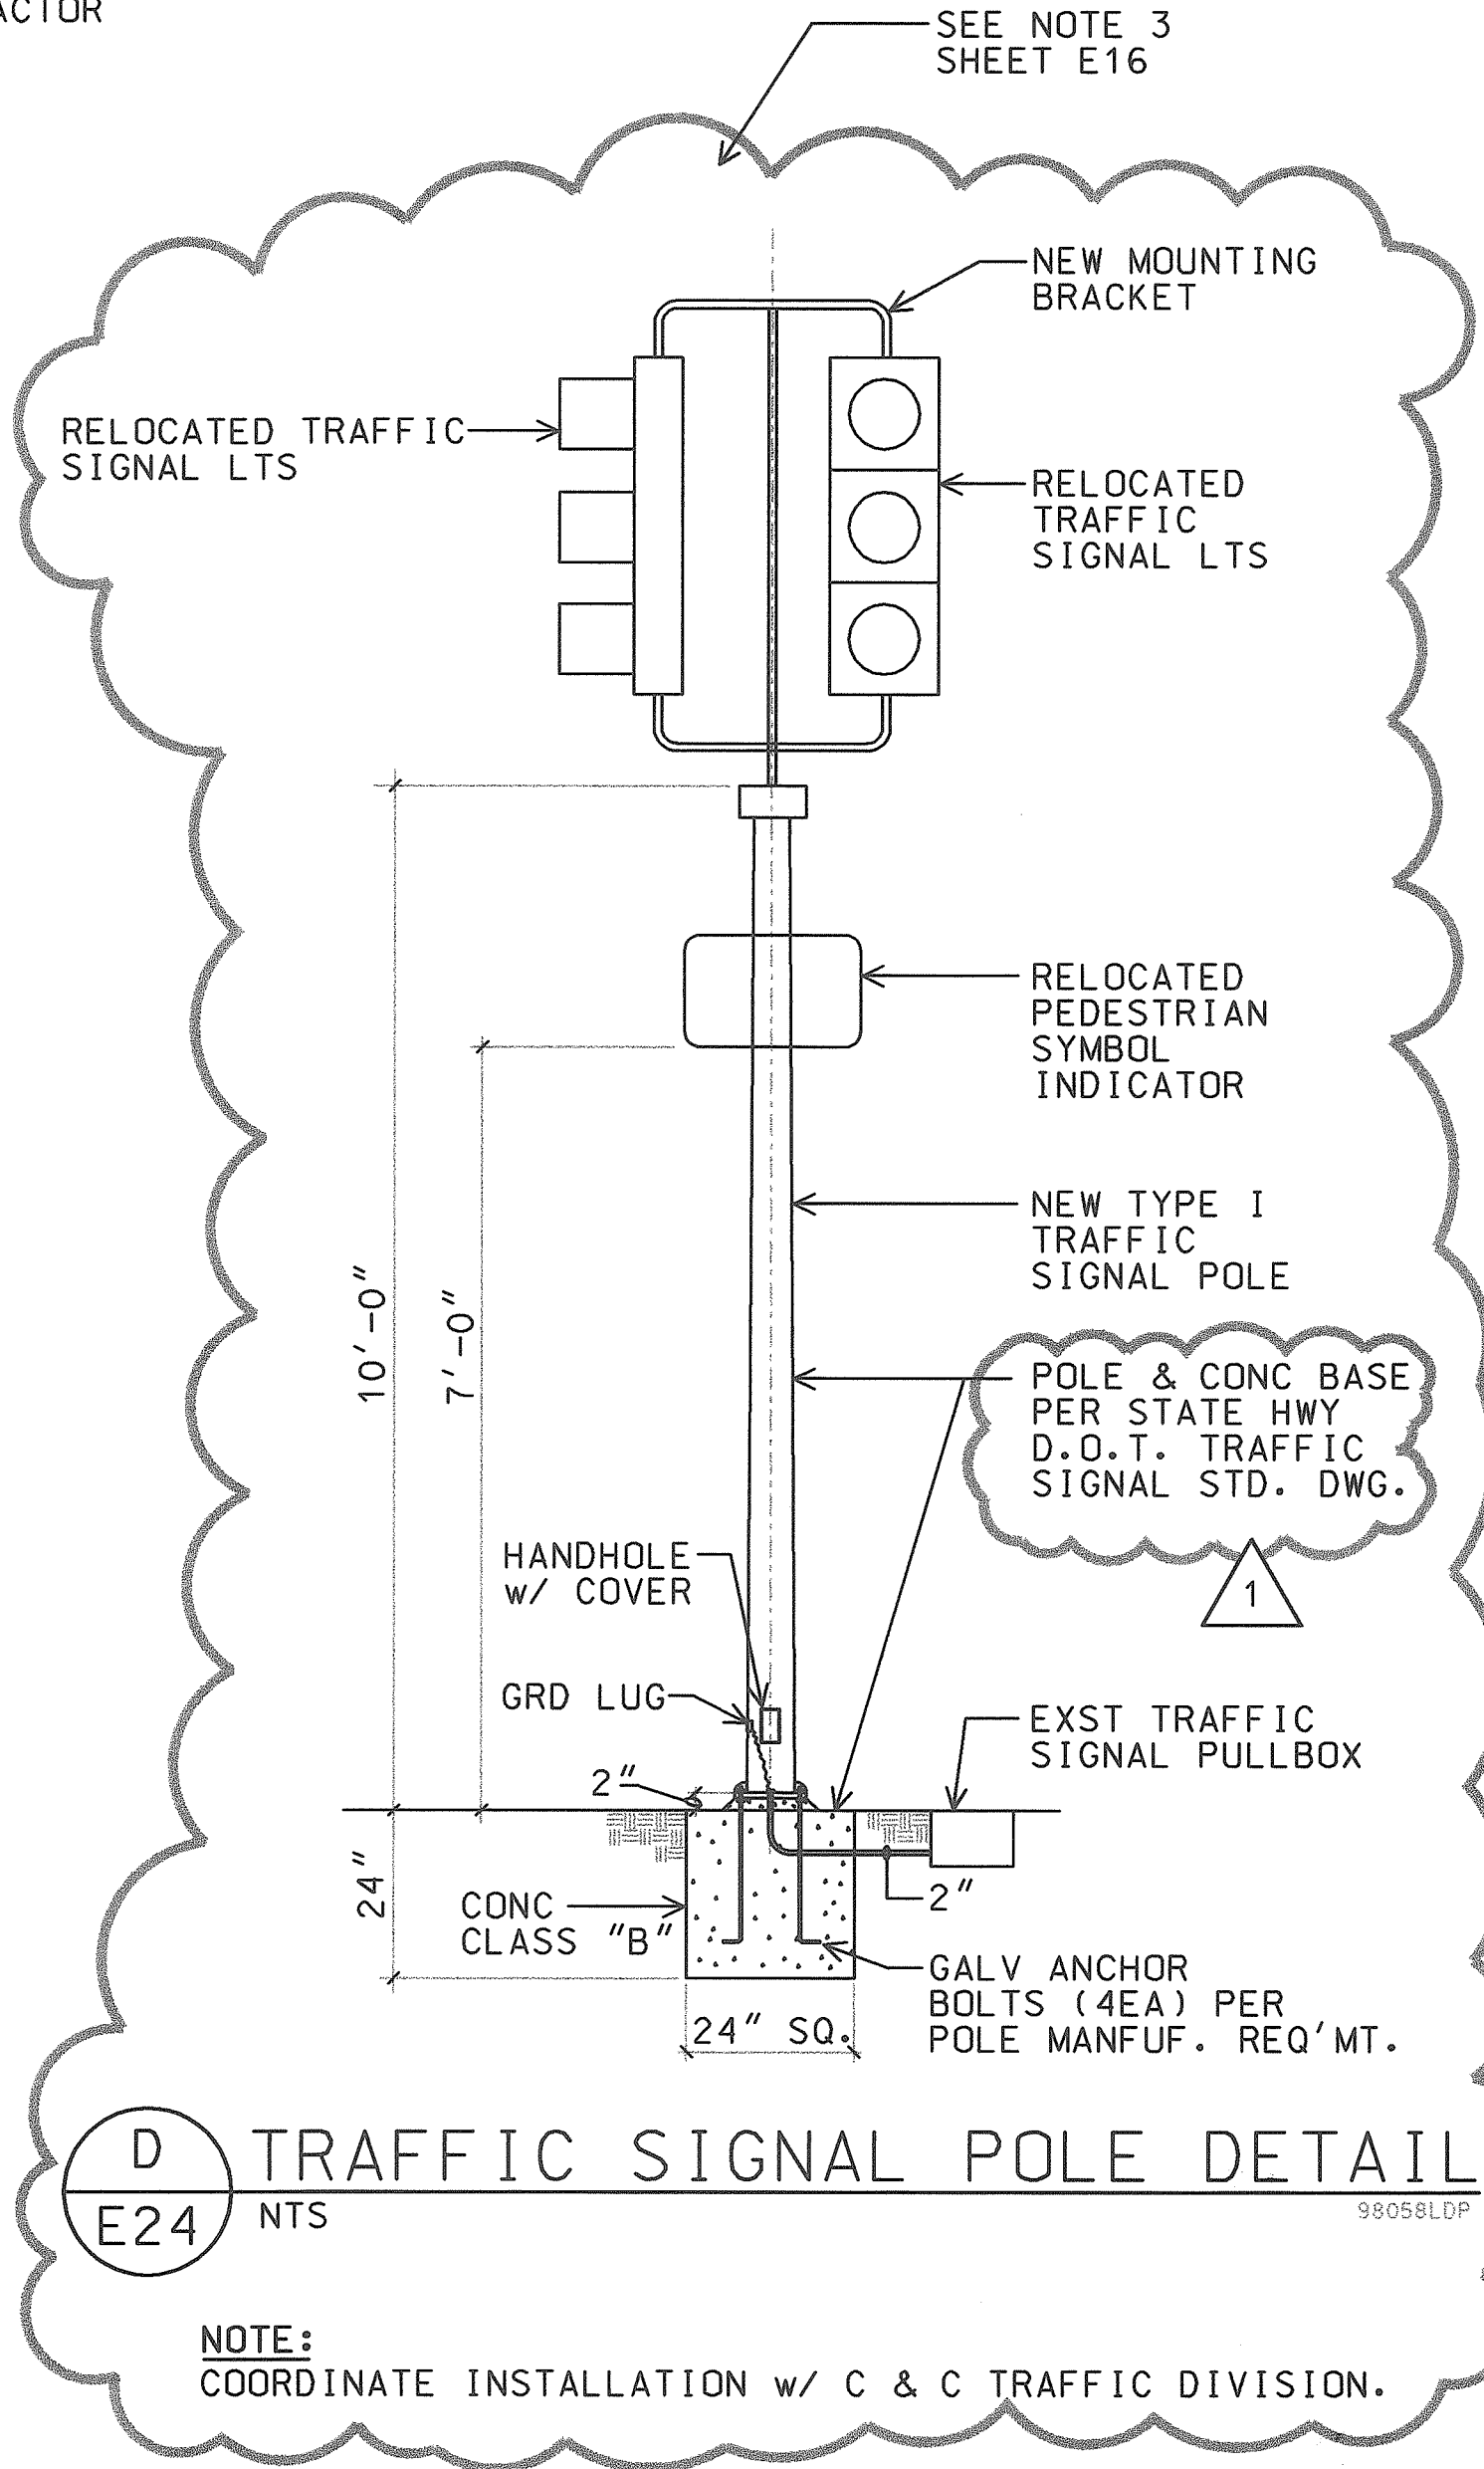


A
E24
METER AND EQUIPMENT CABINET
NTS
98058LDB

C
E24
METER EQUIPMENT ID TAG DETAIL
NTS
98058LDB

D
E24
TRAFFIC SIGNAL POLE DETAIL
NTS
98058LDB

NOTE:
COORDINATE INSTALLATION W/ C & C TRAFFIC DIVISION.

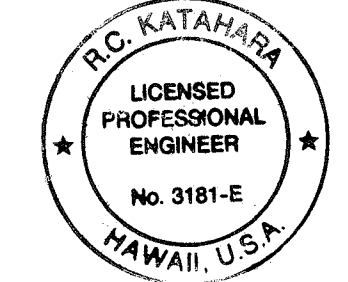

AS-BUILT
2/4/03

THIS WORK WAS PREPARED BY
OR UNDER MY SUPERVISION.
R.C. KATAHARA 11/23/99
MK ENGINEERS, LTD.


DATE	REV	DESCRIPTION
8/16/99	1	ADDED DETAIL NOTES

STATE OF HAWAII
DEPARTMENT OF TRANSPORTATION
HIGHWAYS DIVISION
METER DETAILS
HIGHWAY LIGHTING SAFETY IMPROVEMENTS
LIKELIKE HIGHWAY FROM
SCHOOL STREET TO VALLEY VIEW DRIVE
PROJECT NO. STP-0300(66)
SCALE: AS NOTED DATE: OCTOBER 1998
SHEET No. E24 OF 56 SHEETS


FED. ROAD DIST. NO.	STATE	FED. AID PROJ. NO.	FISCAL YEAR	SHEET NO.	TOTAL SHEETS
HAWAII	HAW.	STP-0300(66)	1998		

NOTES:


- 8 MIL THICK RED COLORED PLASTIC WARNING TAPE 3" WIDE, ENTIRE LENGTH OF DUCT. TAPE TO HAVE CONTINUOUS METALLIC BACKING AND CORROSION RESISTANT FOIL CORE. WARNING AND IDENTIFICATION TO BE IMPRINTED ON TAPE AND SHALL READ "CAUTION BURIED ELECTRIC CABLE BELOW". MESSAGE SHALL BE REPEATED APPROXIMATELY EVERY TEN FEET.
- TYPE "A" BACKFILL: BEACH SAND, EARTH OR EARTH AND GRAVEL USED, THE MAXIMUM ROCK SIZE SHALL BE 1" AND THE MIXTURE SHALL CONTAIN NOT MORE THAN 50% BY VOLUME OF ROCK PARTICLES.
- SAWCUT AT SCORE JOINT. REPLACE CONCRETE SIDEWALK WITHIN THAT AREA. IF SCORE LINE IS LESS THAN 12", SAWCUT THE NEXT CONCRETE SLAB.

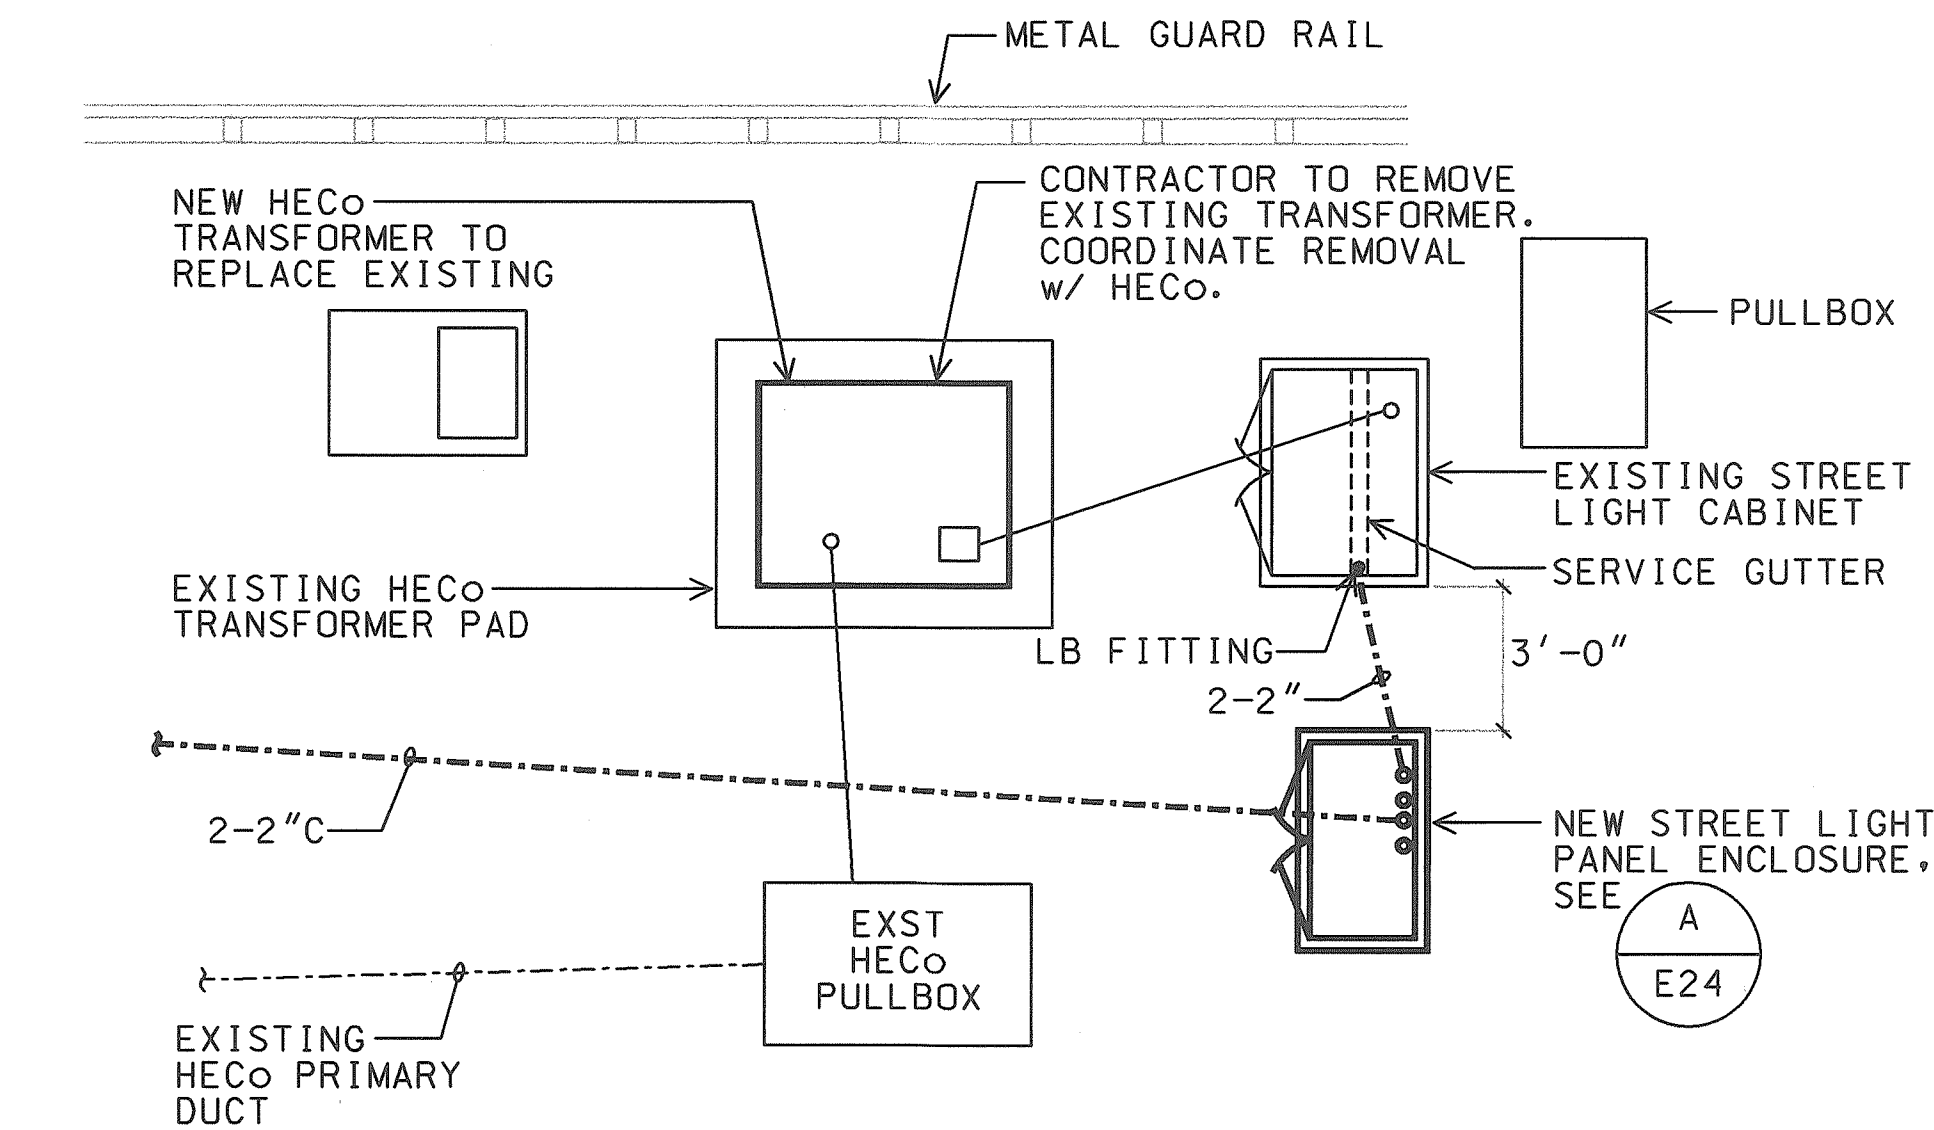

A
E25
SERVICE EQUIPMENT PLAN
SCALE: 1/4" = 1'-0"
98058-LF

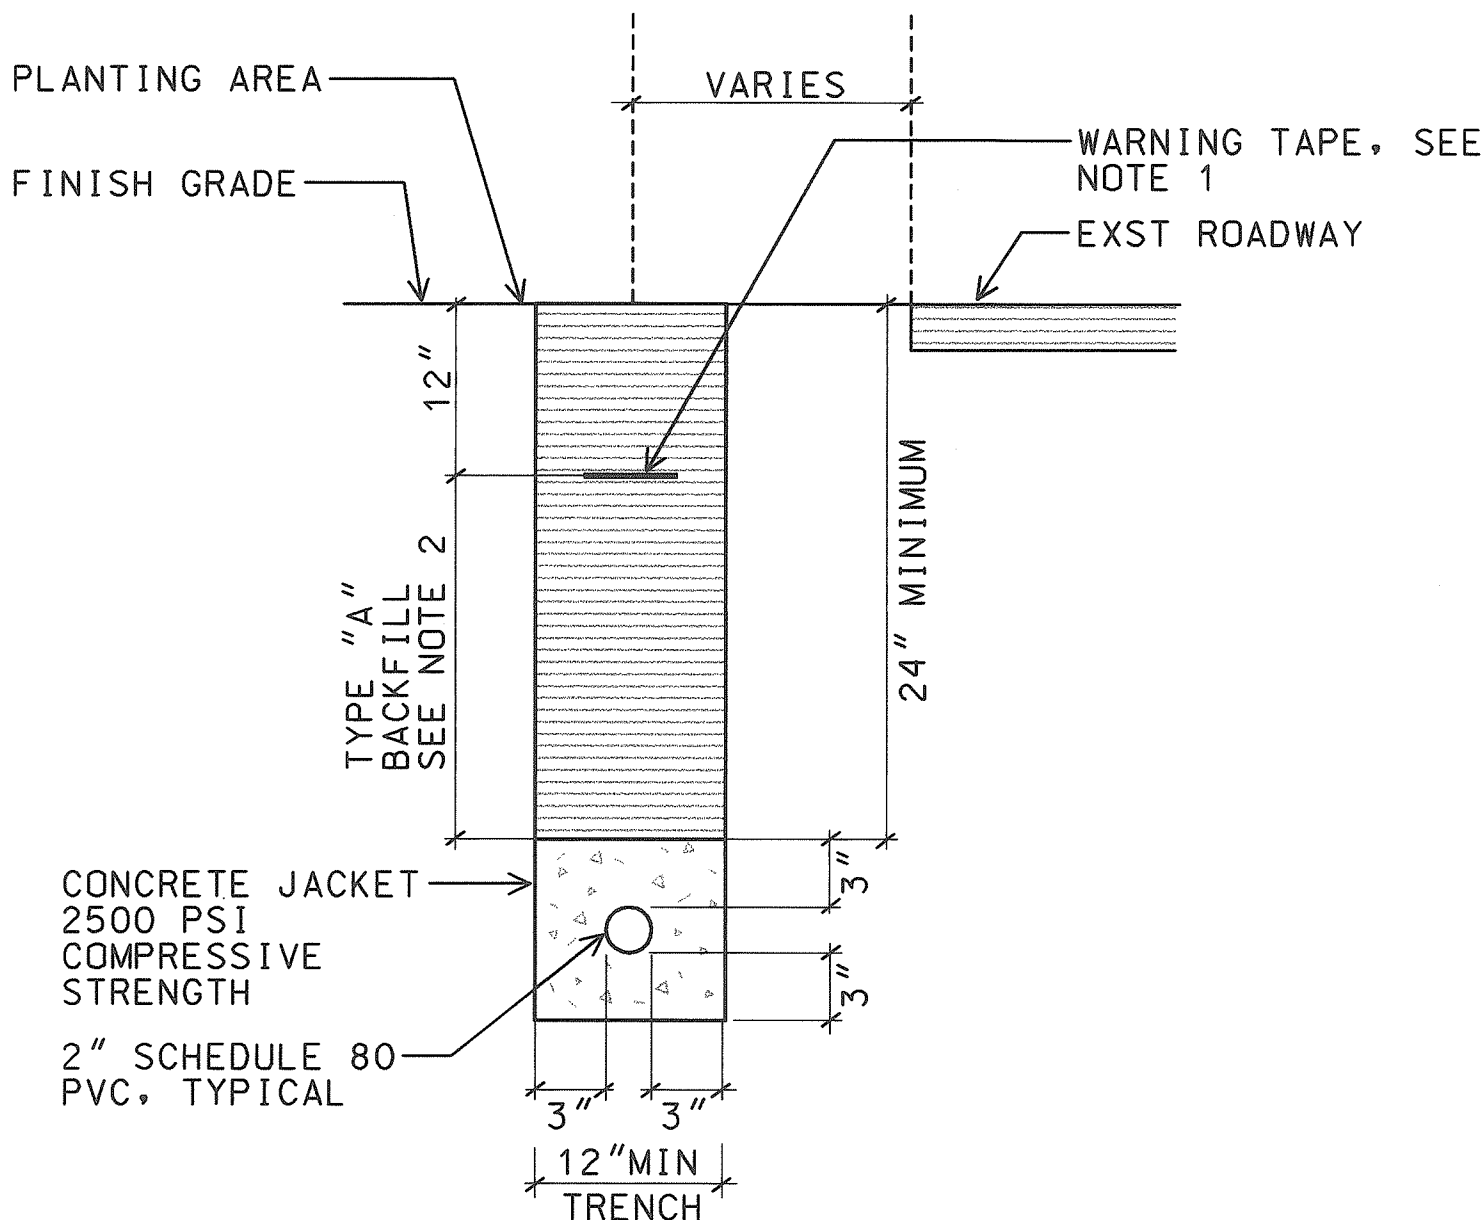


B
E25
CONCRETE ENCASED (NON ROADWAY AREA)
NTS
DUCT SECTION **B1**
E25
SIMILAR EXCEPT WITH 2-2"C OR 2-4"C.
98058-DG

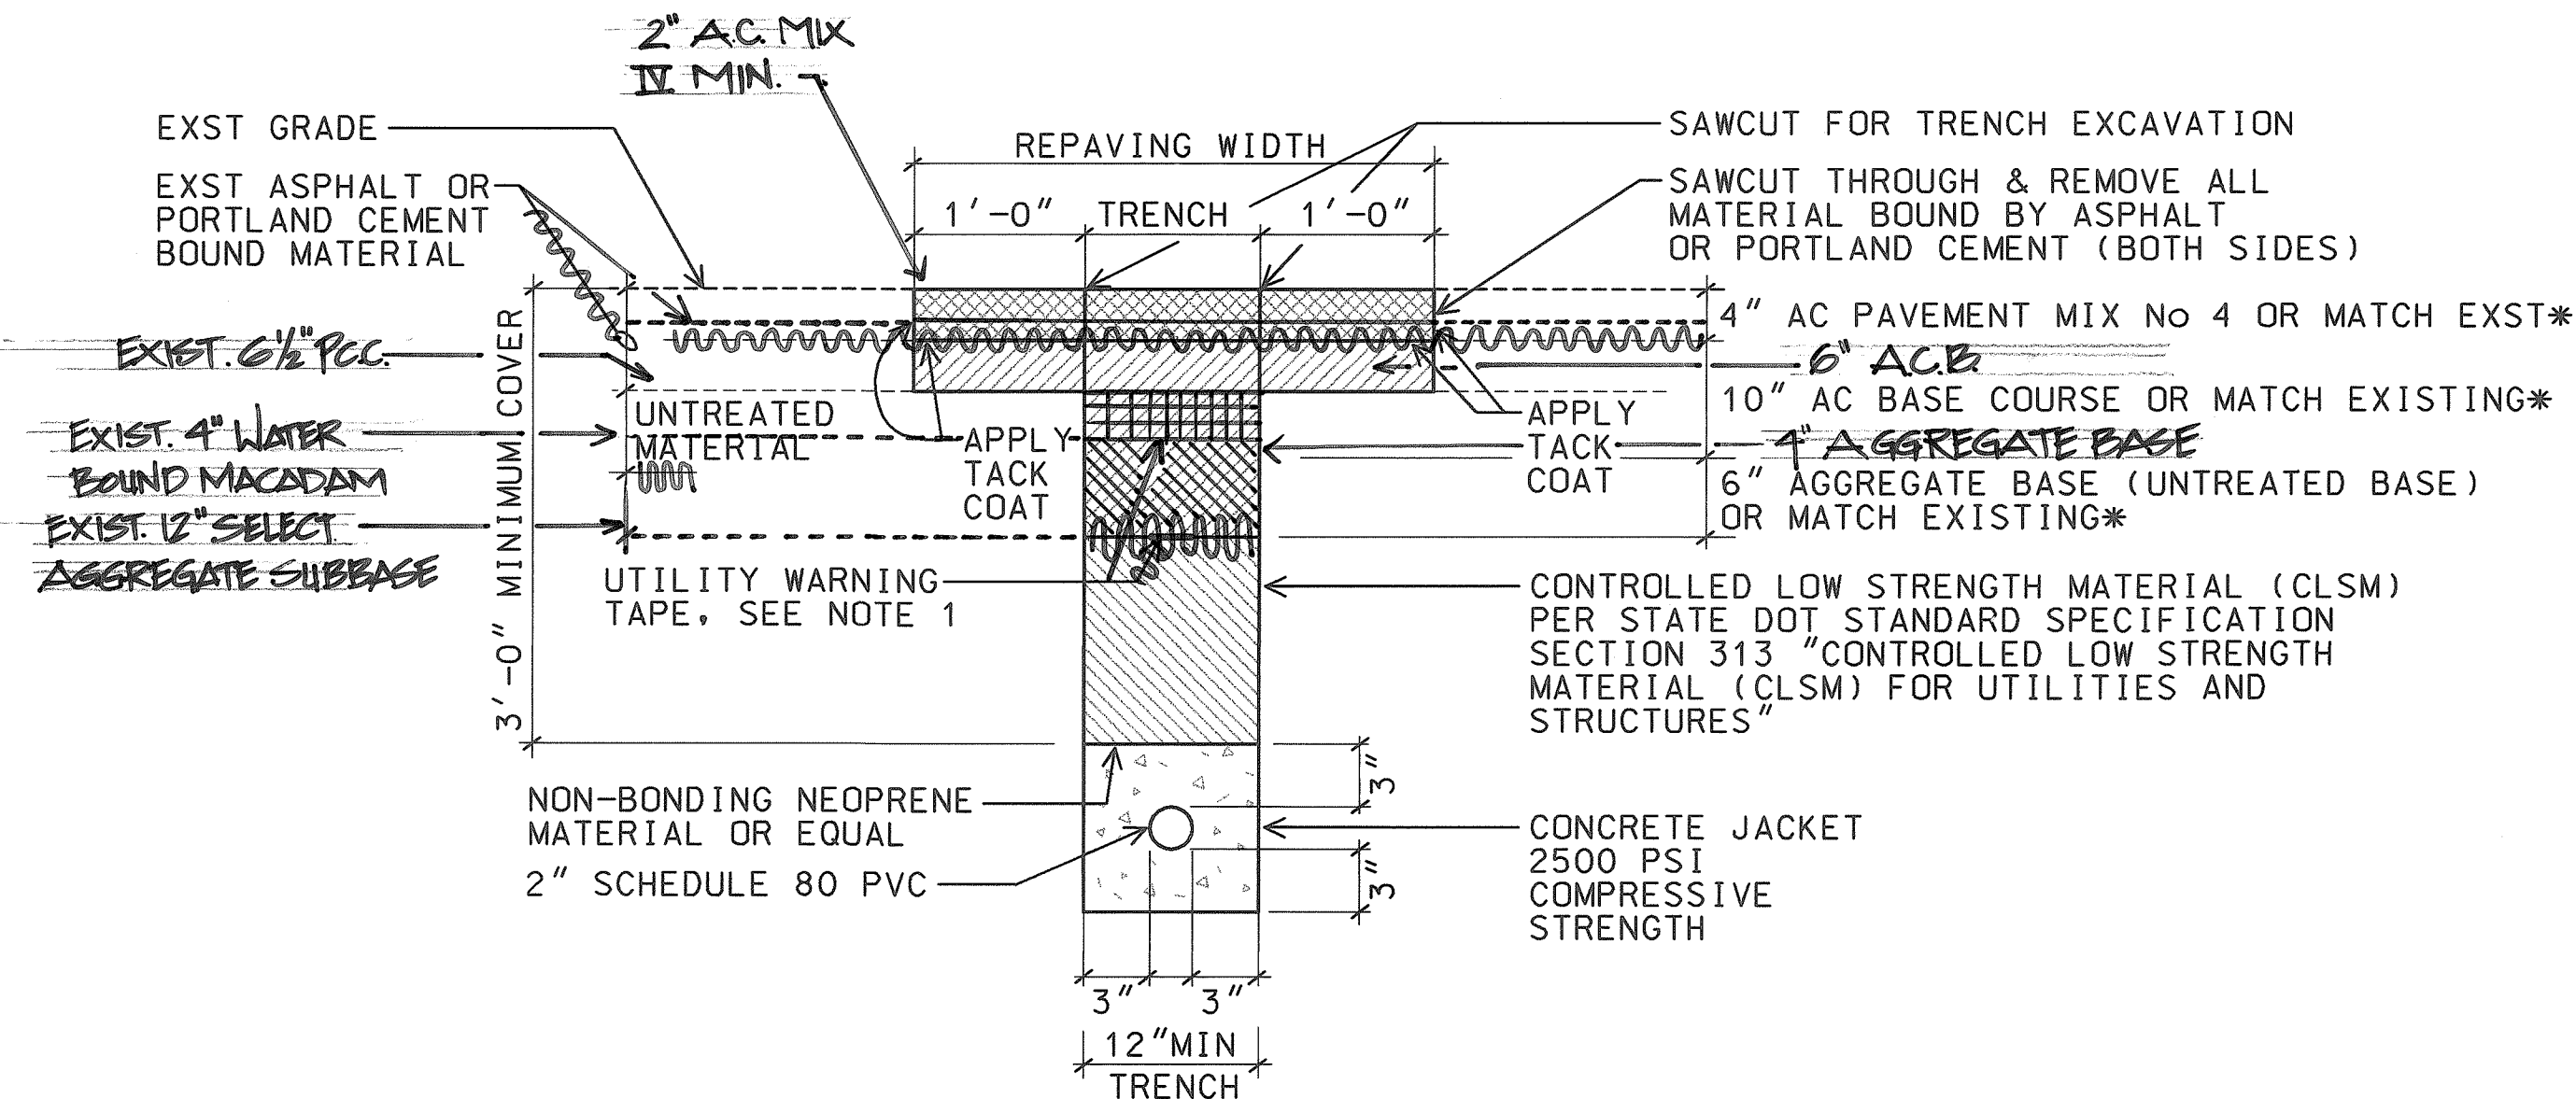


* MINIMUM THICKNESS OR REPLACE TO EXISTING THICKNESS IF GREATER.

C
E25
TYPICAL PAVEMENT RESTORATION IN STATE HIGHWAY
NTS
DUCT SECTION **C1**
E25
SIMILAR EXCEPT WITH 2-2"C.
98058-DG

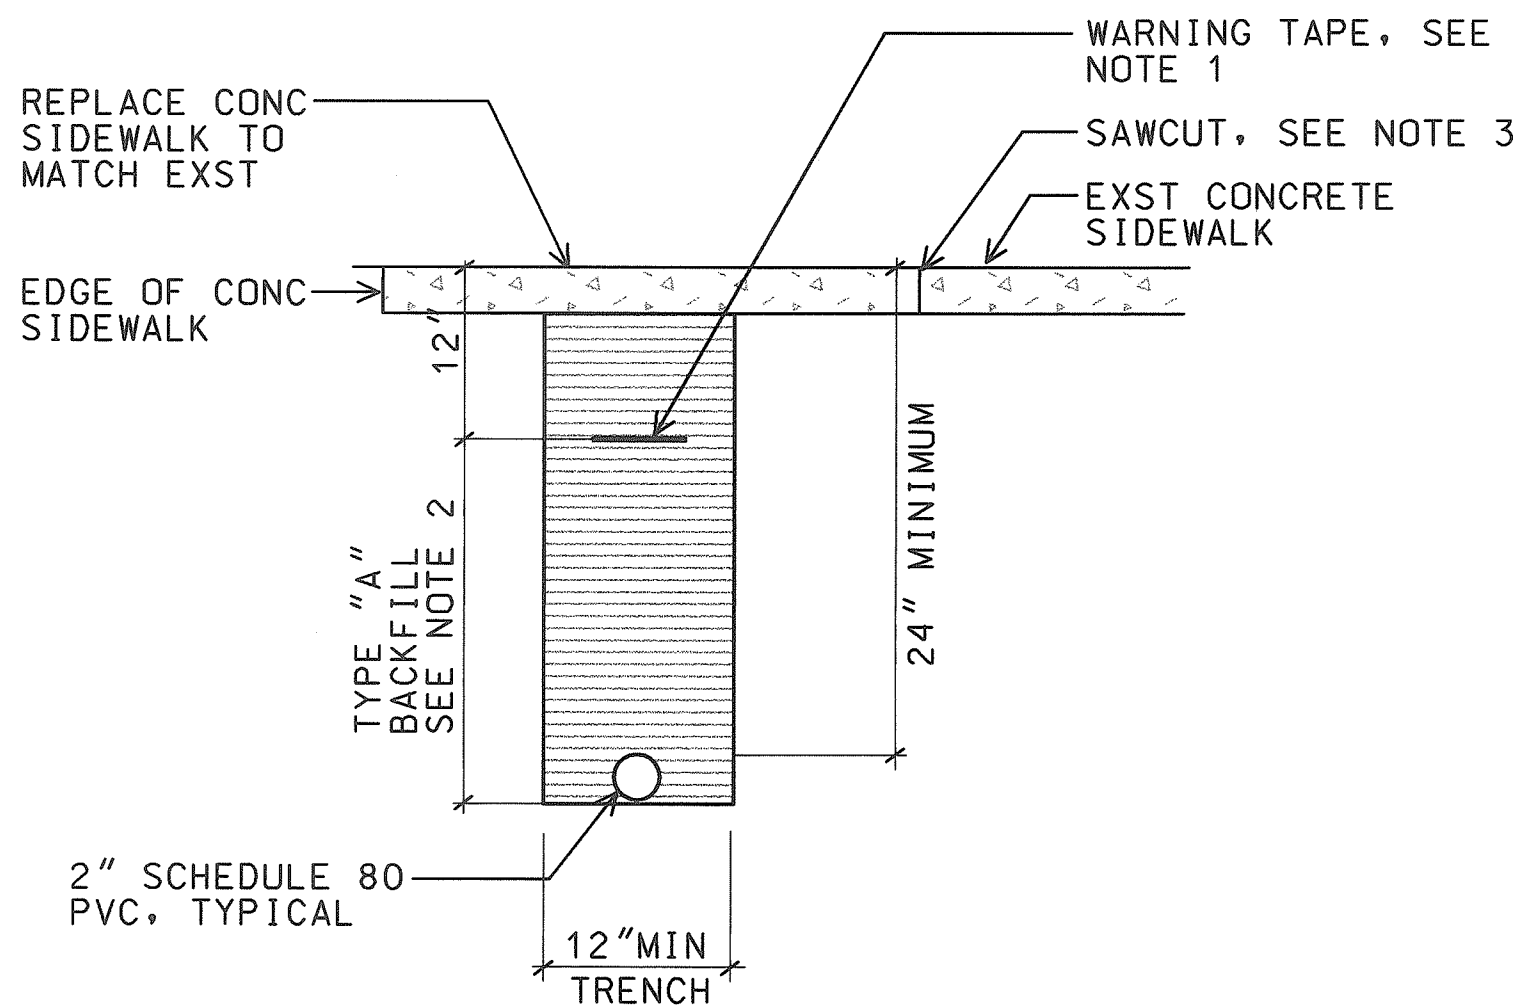

D
E25
DIRECT BURIED CONDUIT (UNDER CONC. SIDEWALK)
NTS
98058-DG

AS-BUILT
DATE
2/4/03

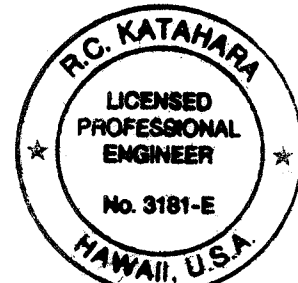


THIS WORK WAS PREPARED BY ME
OR UNDER MY SUPERVISION.
R.C. KATAHARA 11/25/98
MK ENGINEERS, LTD.

DATE	REV	DESCRIPTION
8/16/99	1	REV. WARNING TAPE
STATE OF HAWAII DEPARTMENT OF TRANSPORTATION HIGHWAYS DIVISION MISCELLANEOUS DETAILS HIGHWAY LIGHTING SAFETY IMPROVEMENTS LIKELIKE HIGHWAY FROM SCHOOL STREET TO VALLEY VIEW DRIVE PROJECT NO. STP-0300(66) SCALE: AS NOTED DATE: OCTOBER 1998 SHEET No. E25 OF 56 SHEETS		

C0-E25


FED. ROAD DIST. NO.	STATE	FED. AID PROJ. NO.	FISCAL YEAR	SHEET NO.	TOTAL SHEETS
HAWAII	HAW.	STP-0300(66)	1998		

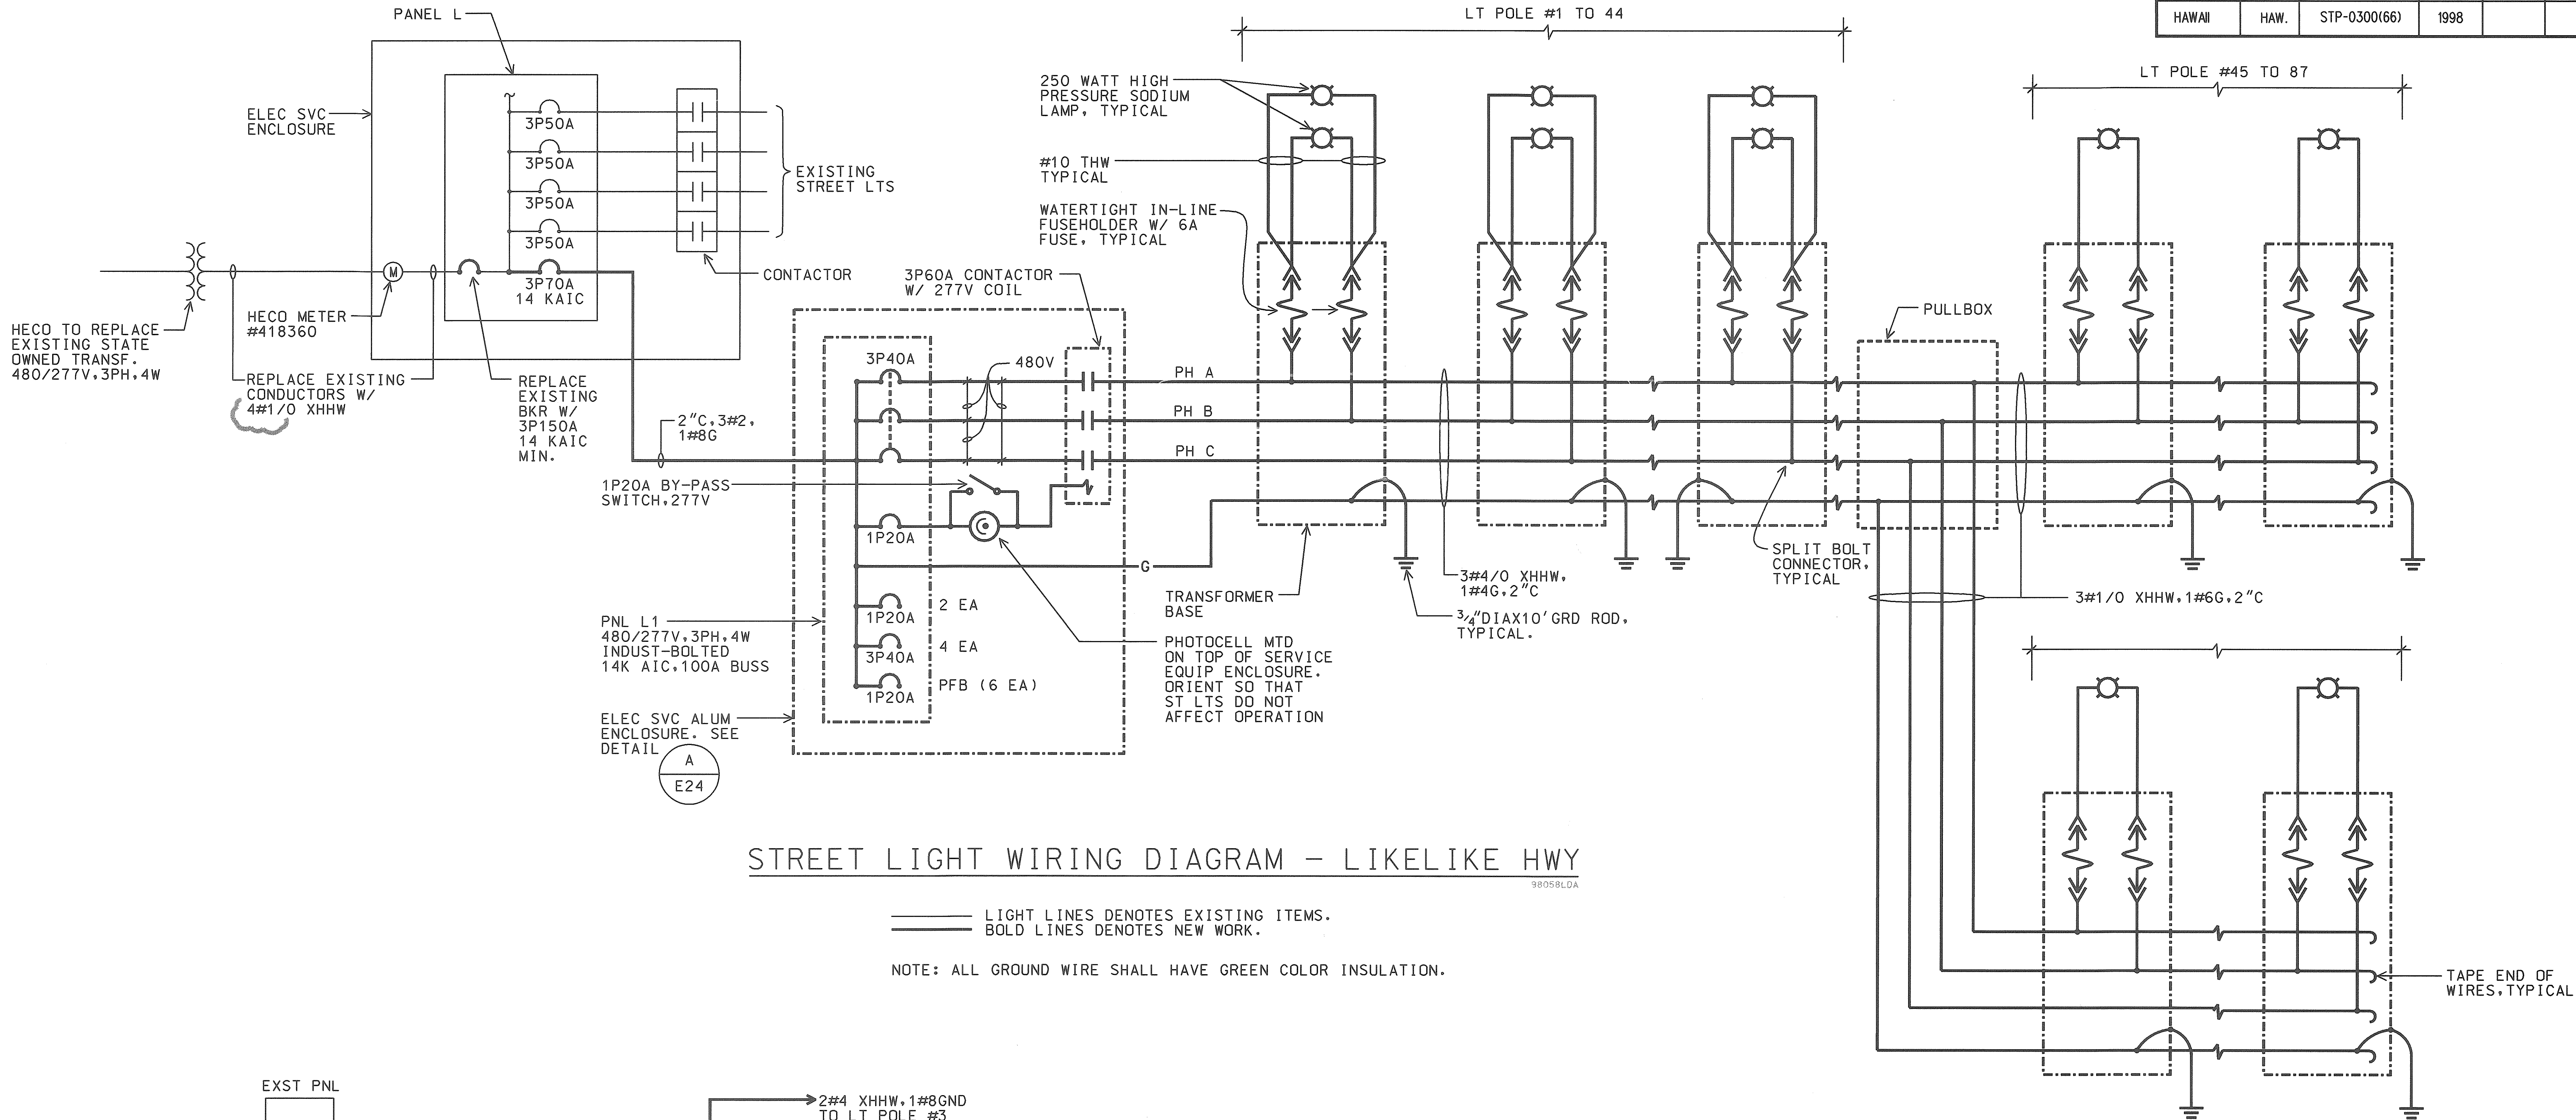

STREET LIGHT WIRING DIAGRAM - LIKELIKE HWY


— LIGHT LINES DENOTES EXISTING ITEMS.
— BOLD LINES DENOTES NEW WORK.

NOTE: ALL GROUND WIRE SHALL HAVE GREEN COLOR INSULATION.

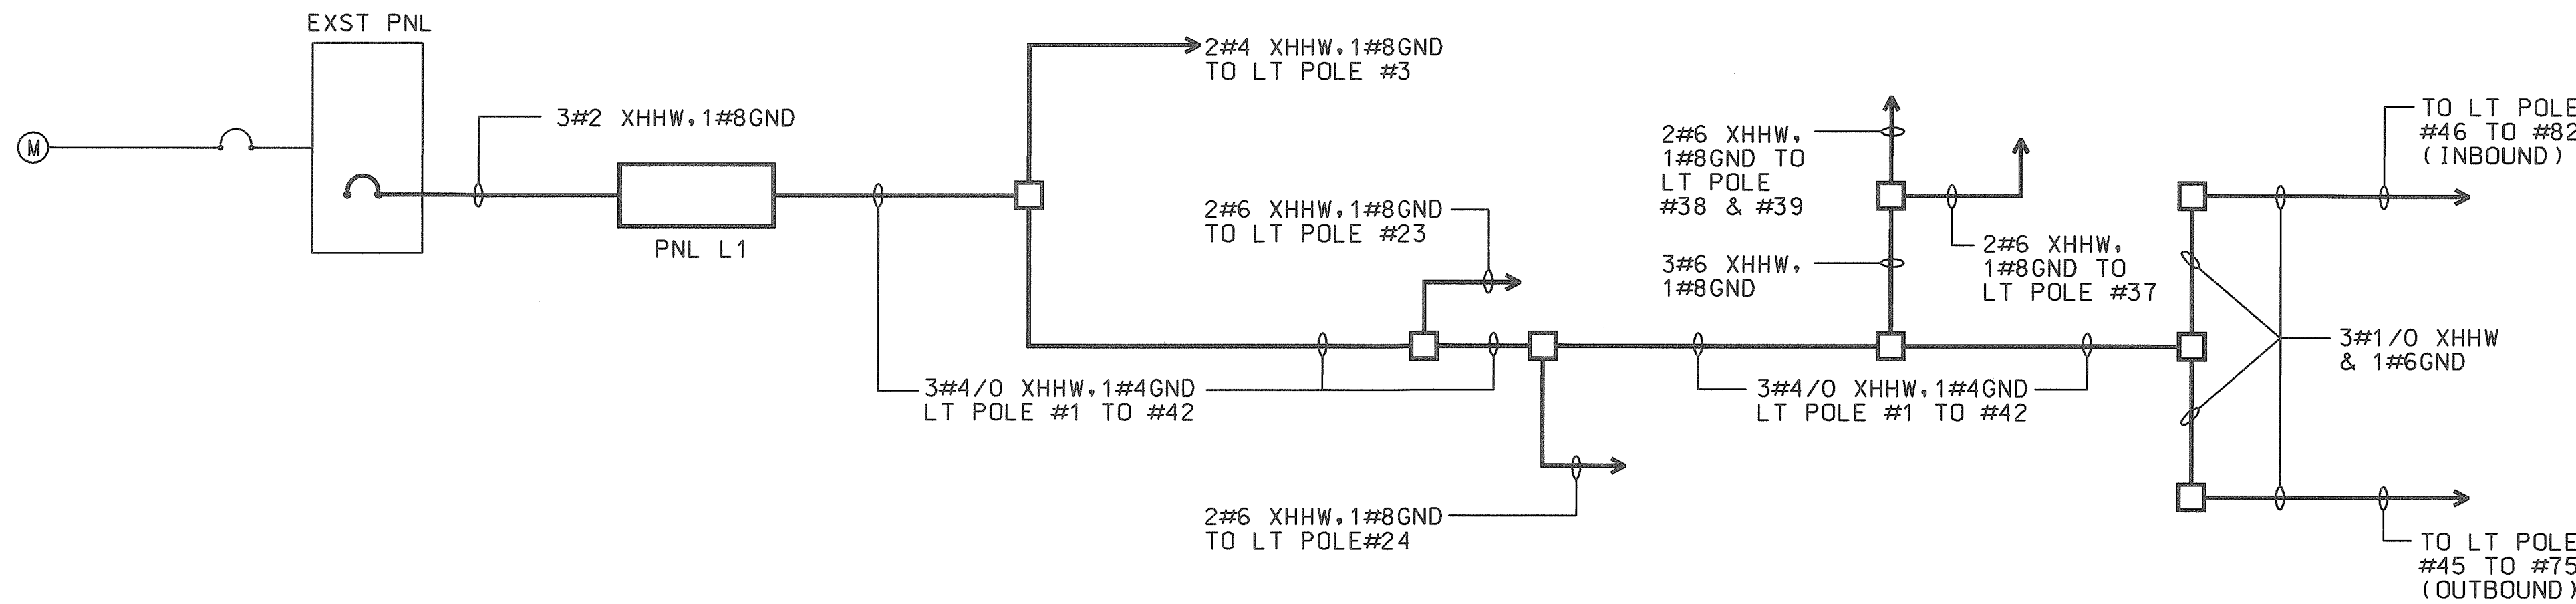

ONE - LINE DIAGRAM

— BOLD LINES DENOTES NEW WORK.

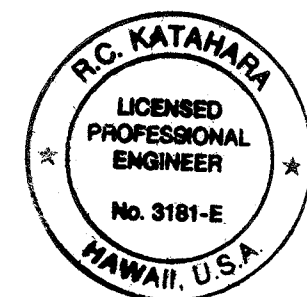

THIS WORK WAS PREPARED BY ME
OR UNDER MY SUPERVISION.
R.C. KATAHARA 11/25/98
MK ENGINEERS, LTD.


STATE OF HAWAII
DEPARTMENT OF TRANSPORTATION
HIGHWAYS DIVISION
STREET LIGHT WIRING DIAGRAM
HIGHWAY LIGHTING SAFETY IMPROVEMENTS
LIKELIKE HIGHWAY FROM
SCHOOL STREET TO VALLEY VIEW DRIVE
PROJECT NO. STP-0300(66)
SCALE: AS NOTED DATE: OCTOBER 1998
SHEET No. E26 OF 56 SHEETS

AS-BUILT
9/4/03
DATE

ELECTRICAL SYMBOLS


- NEW STREET LIGHT STANDARD & CONCRETE BASE WITH DOUBLE ARM & 250W HPS LUMINAIRES. SEE DETAIL
- STREET LIGHT PULLBOX, SEE DETAIL
- NEW STREET LIGHT STANDARD & CONCRETE BASE WITH SINGLE ARM & 250W HPS LUMINAIRE, SEE DETAIL
-
- EXISTING STREET LIGHT LUMINAIRE & BRACKET ARM ON WOOD POLE
-
-
- REMOVE EXISTING CONDUCTORS. ABANDON CONDUIT IN PLACE
- REMOVE EXISTING OVERHEAD STREET LIGHT CONDUCTORS
-

FED. ROAD DIST. NO.	STATE	FED. AID PROJ. NO.	FISCAL YEAR	SHEET NO.	TOTAL SHEETS
HAWAII	HAW.	STP-0300(66)	1998		

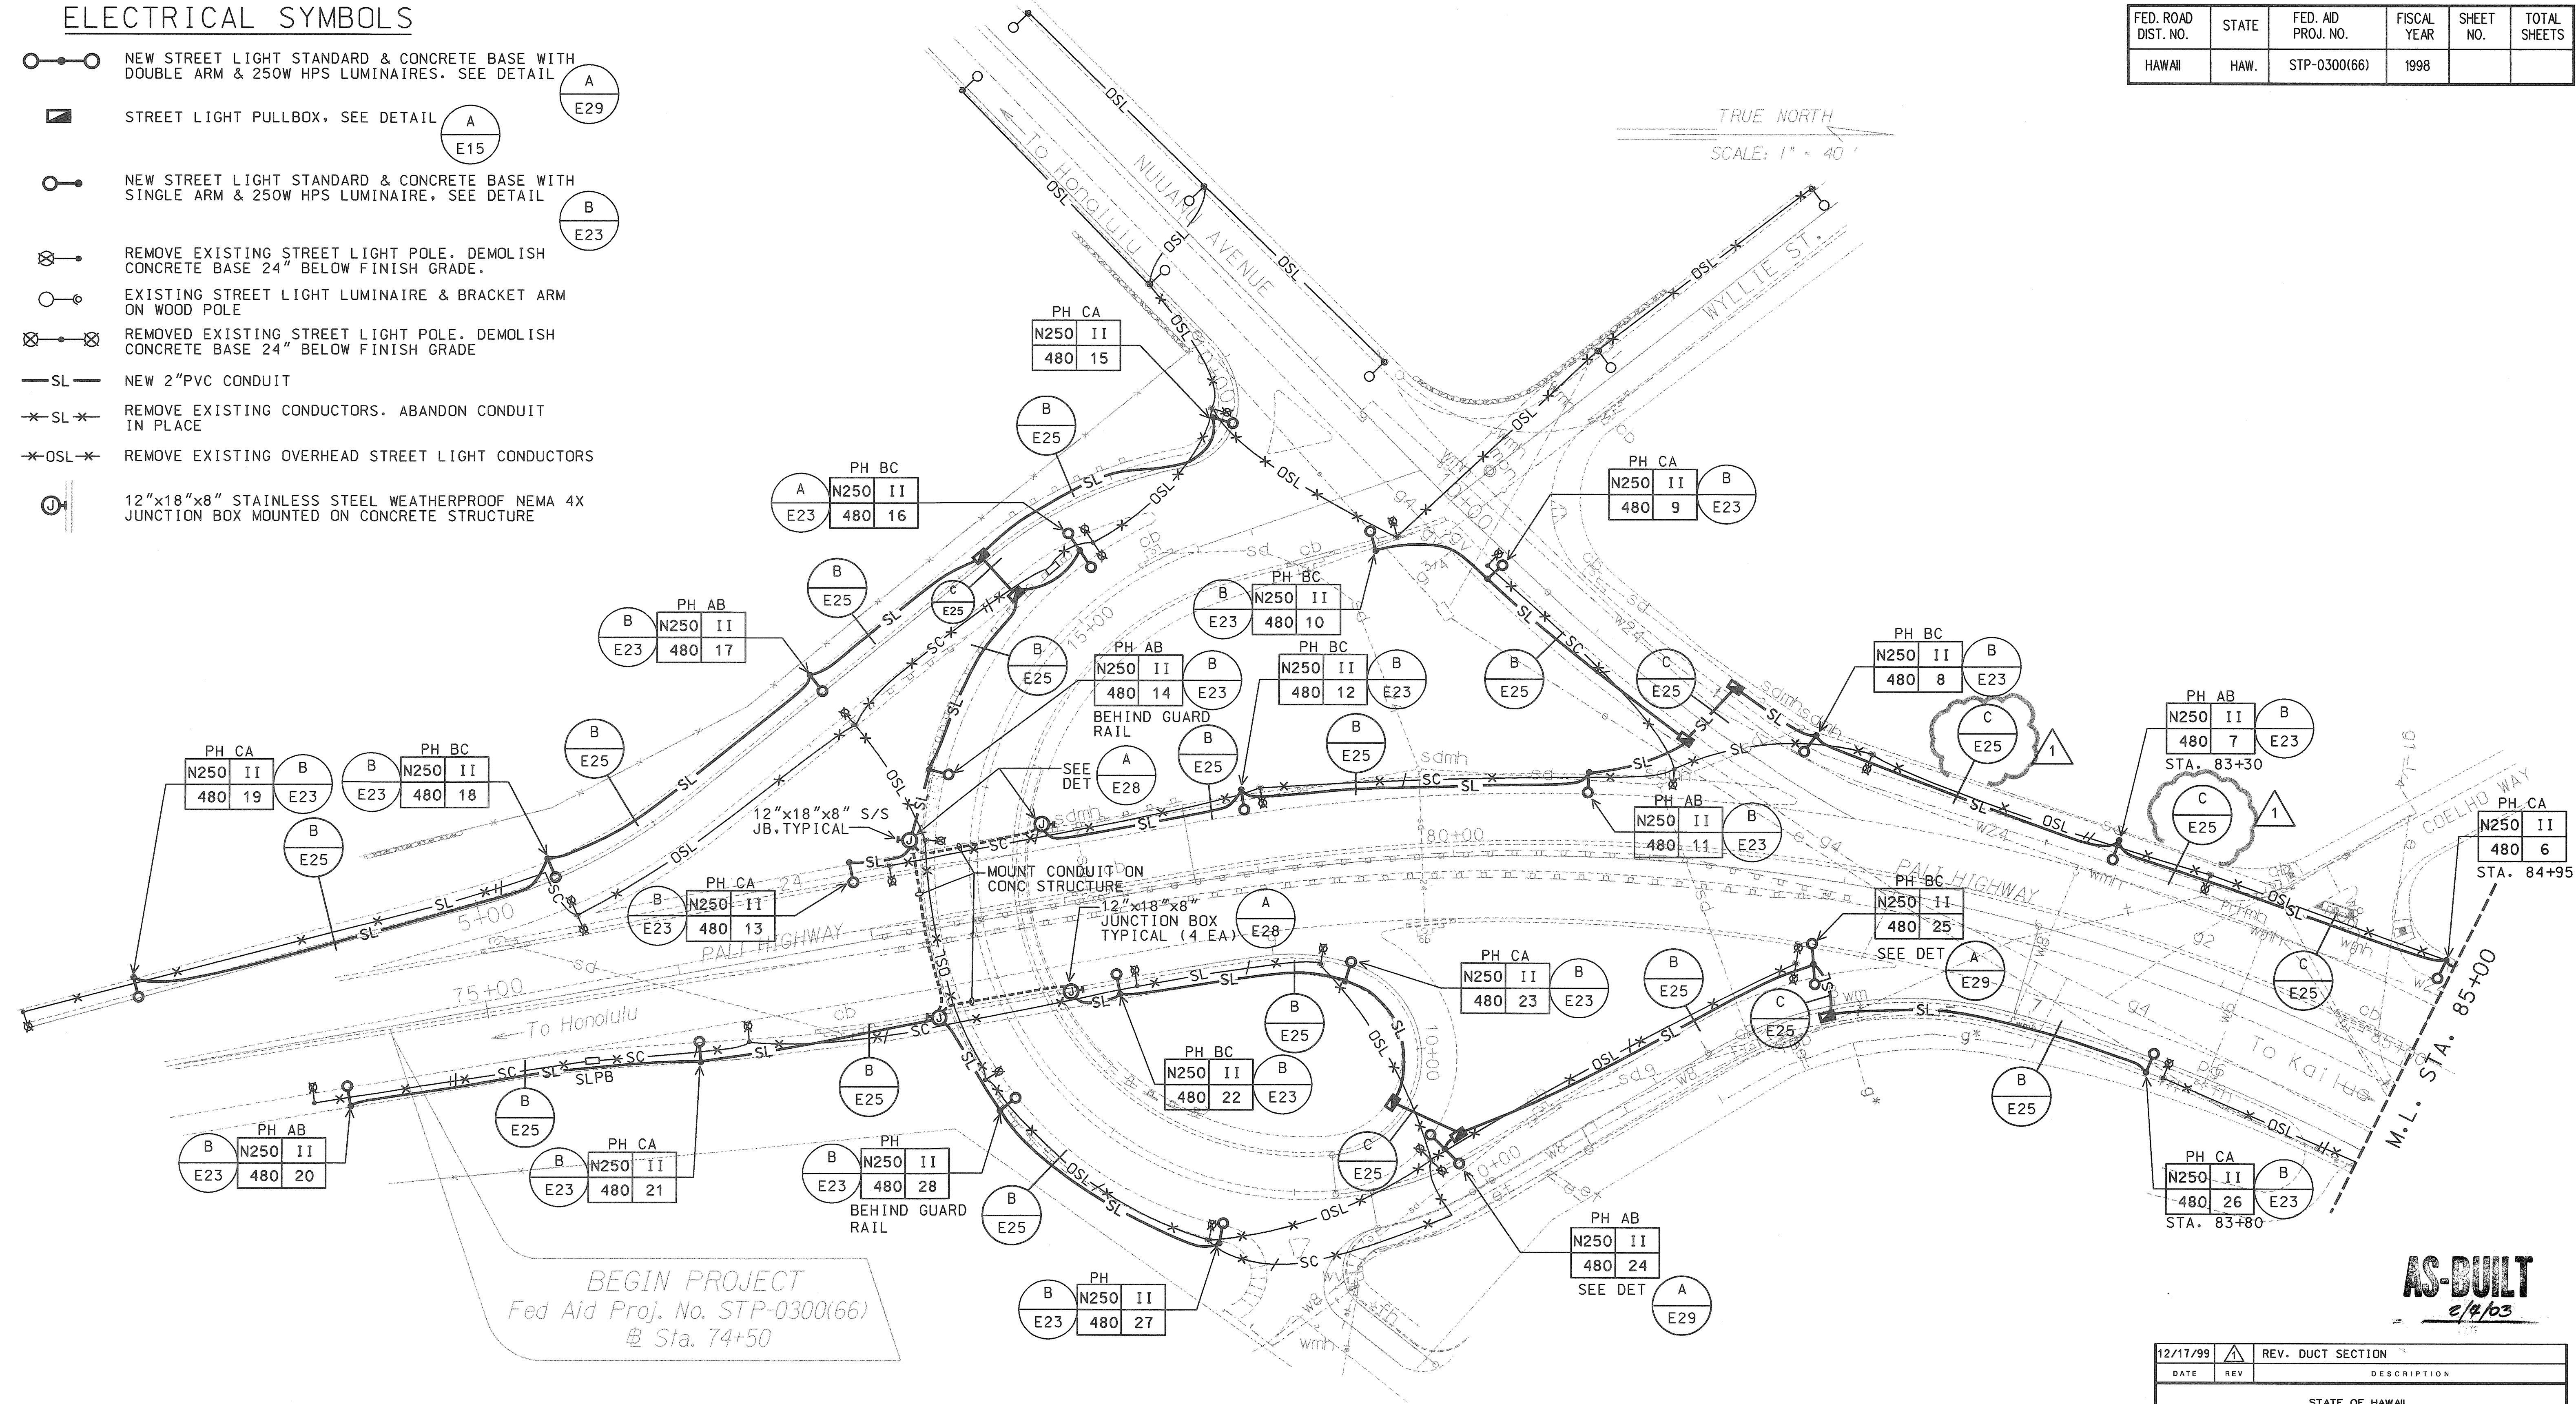

HIGHWAY LIGHTING PLAN



SCALE: 1" = 40'

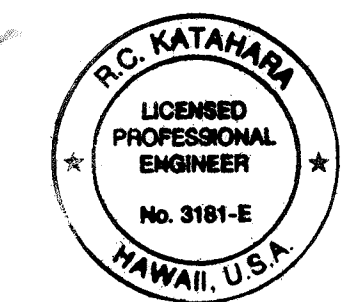

THIS WORK WAS PREPARED BY ME OR UNDER MY SUPERVISION.
R.C. KATAHARA 11/25/98
MK ENGINEERS, LTD.

DATE	REV	DESCRIPTION
12/17/99	1	REV. DUCT SECTION
STATE OF HAWAII DEPARTMENT OF TRANSPORTATION HIGHWAYS DIVISION HIGHWAY LIGHTING PLAN HIGHWAY LIGHTING SAFETY IMPROVEMENTS PALI HIGHWAY VICINITY OF WYLLIE INTERCHANGE TO JACK LANE PROJECT NO. STP-0300(66) SCALE: AS NOTED DATE: OCTOBER 1998 SHEET No. E27 OF 56 SHEETS		


FED. ROAD DIST. NO.	STATE	FED. AID PROJ. NO.	FISCAL YEAR	SHEET NO.	TOTAL SHEETS
HAWAII	HAW.	STP-0300(66)	1998		

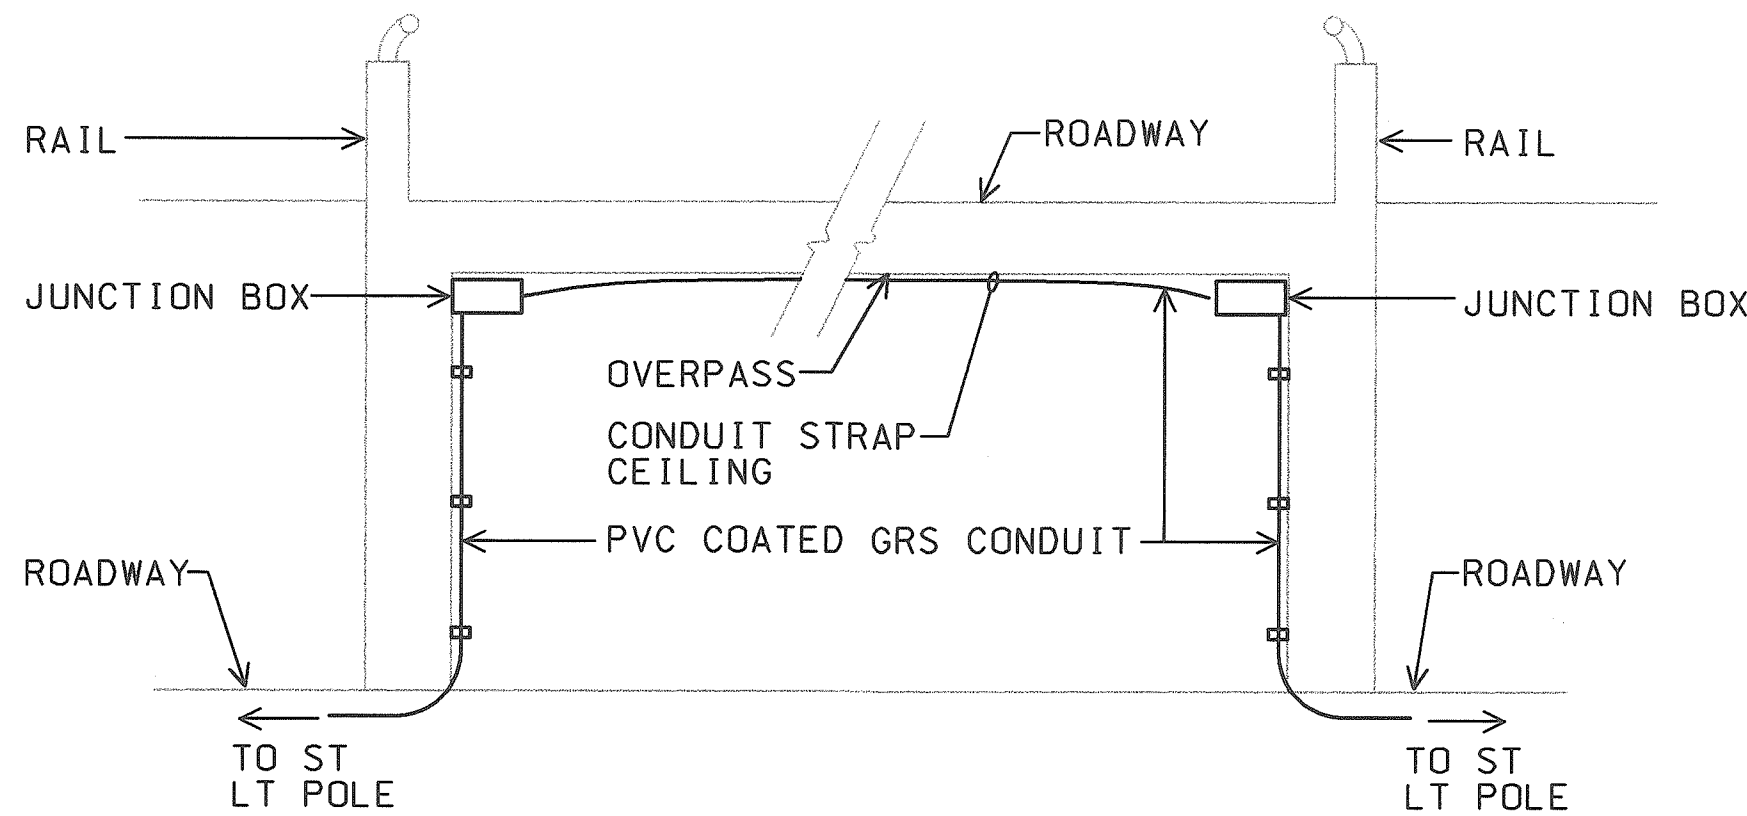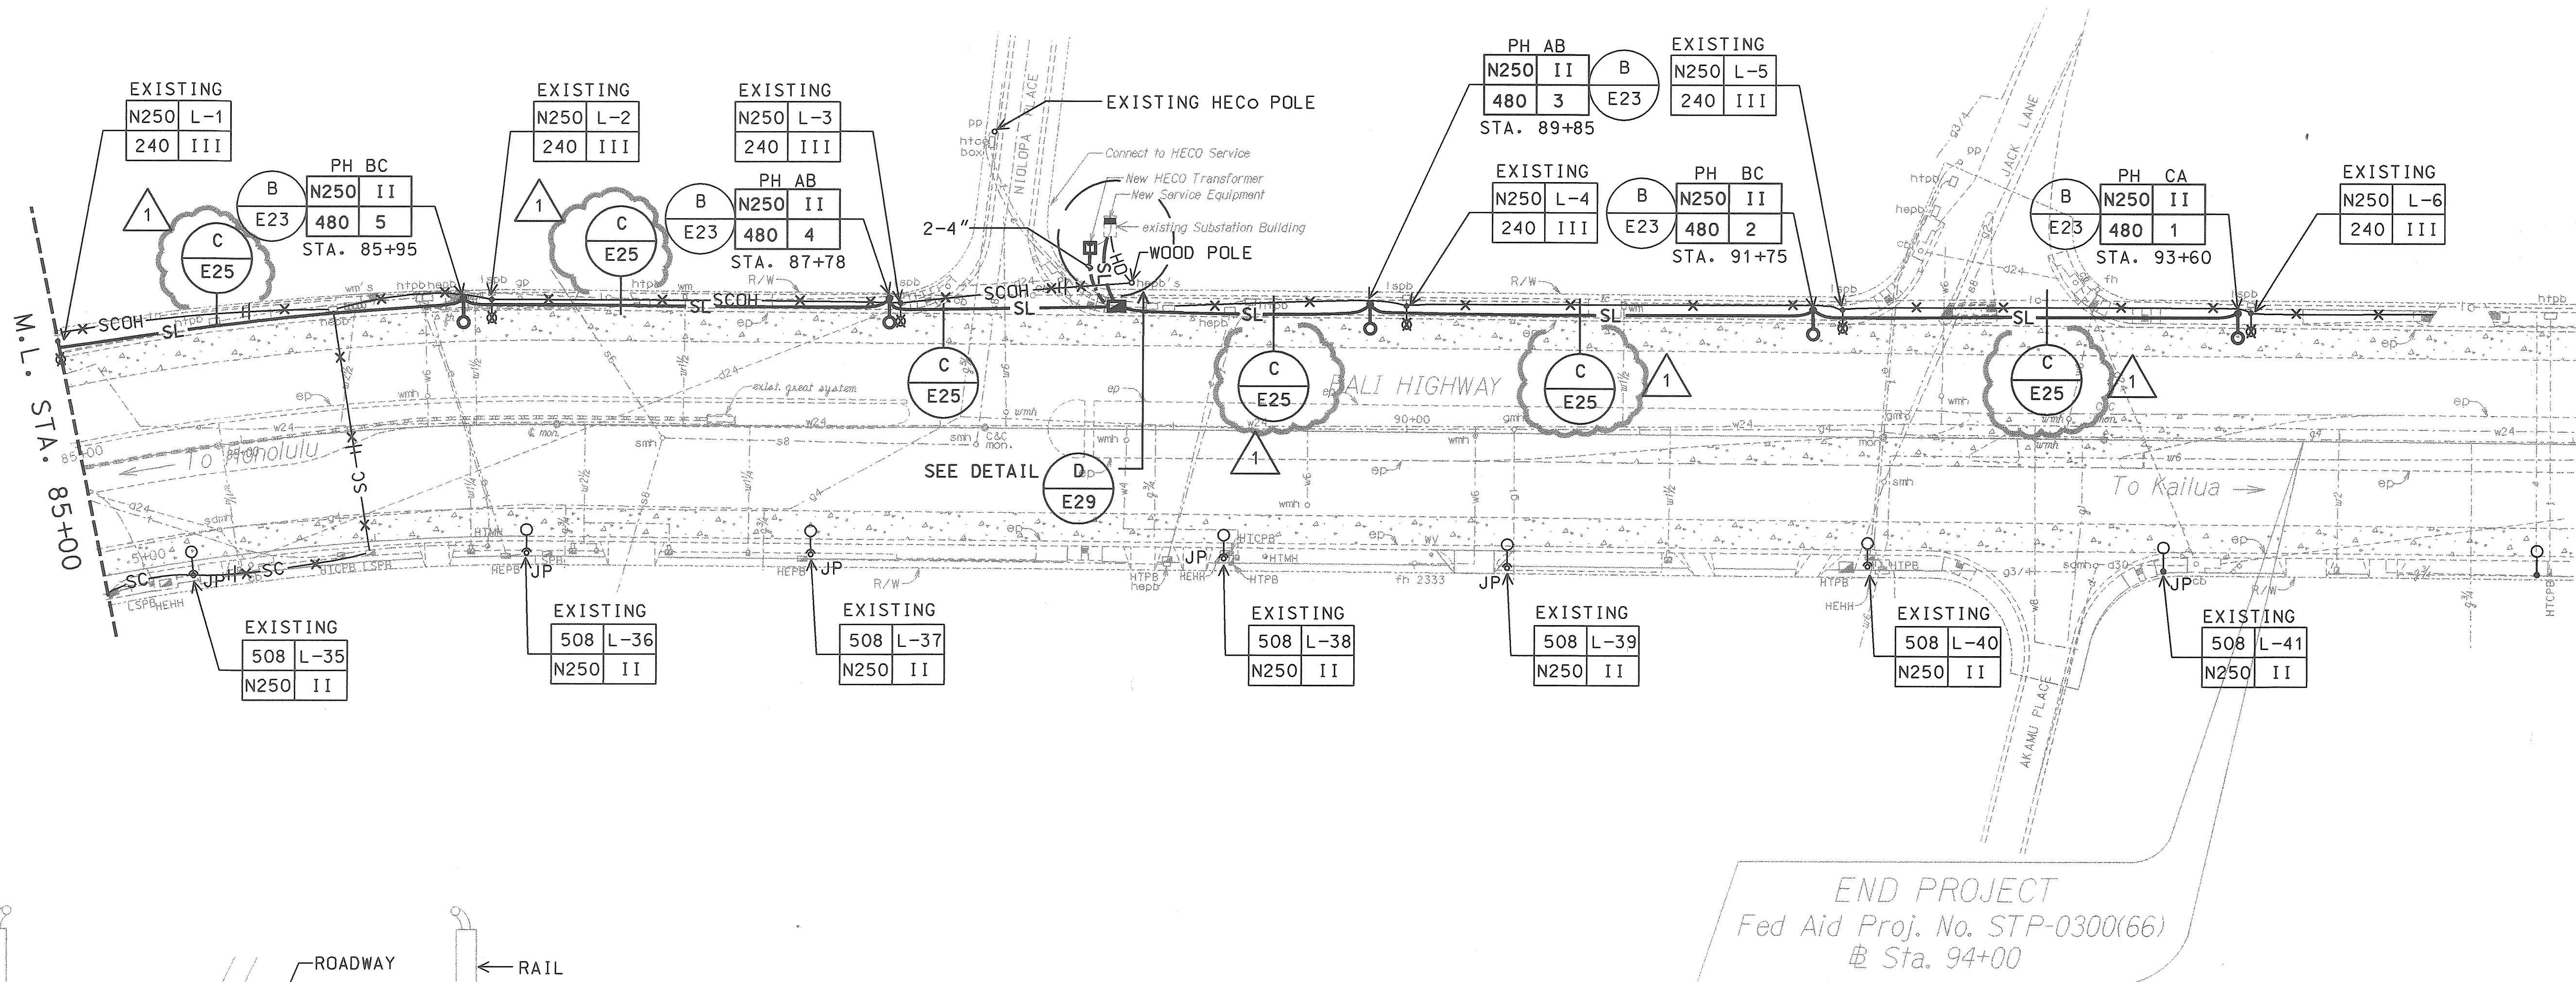

HIGHWAY LIGHTING PLAN

SCALE: 1" = 40'

- NOTES:
1. REMOVE EXISTING LT POLES L-1 TO L-6 AND REMOVE WIRES FROM LT POLES L-1 TO L-7. ABANDON CONDUIT IN PLACE.
 2. EXISTING L-35 TO L-41 ARE CONNECTED TO HECO SECONDARY CABLES.

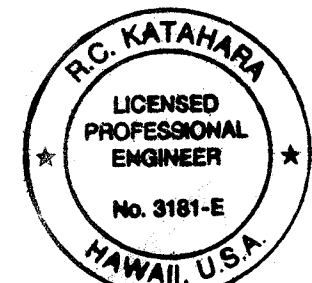


THIS WORK WAS PREPARED BY ME OR UNDER MY SUPERVISION.
R.C. KATAHARA 11/25/98
 MK ENGINEERS, LTD.


DATE	REV	DESCRIPTION
12/17/99	1	REV. DUCT SECTION
STATE OF HAWAII DEPARTMENT OF TRANSPORTATION HIGHWAYS DIVISION		
HIGHWAY LIGHTING PLAN		
HIGHWAY LIGHTING SAFETY IMPROVEMENTS PALI HIGHWAY VICINITY OF WYLLIE INTERCHANGE TO JACK LANE		
PROJECT NO. STP-0300(66)		
SCALE: AS NOTED		DATE: OCTOBER 1998
SHEET No. E28 OF 56 SHEETS		

AS-BUILT
 2/4/03


FED. ROAD DIST. NO.	STATE	FED. AID PROJ. NO.	FISCAL YEAR	SHEET NO.	TOTAL SHEETS
HAWAII	HAW.	STP-0300(66)	1998		

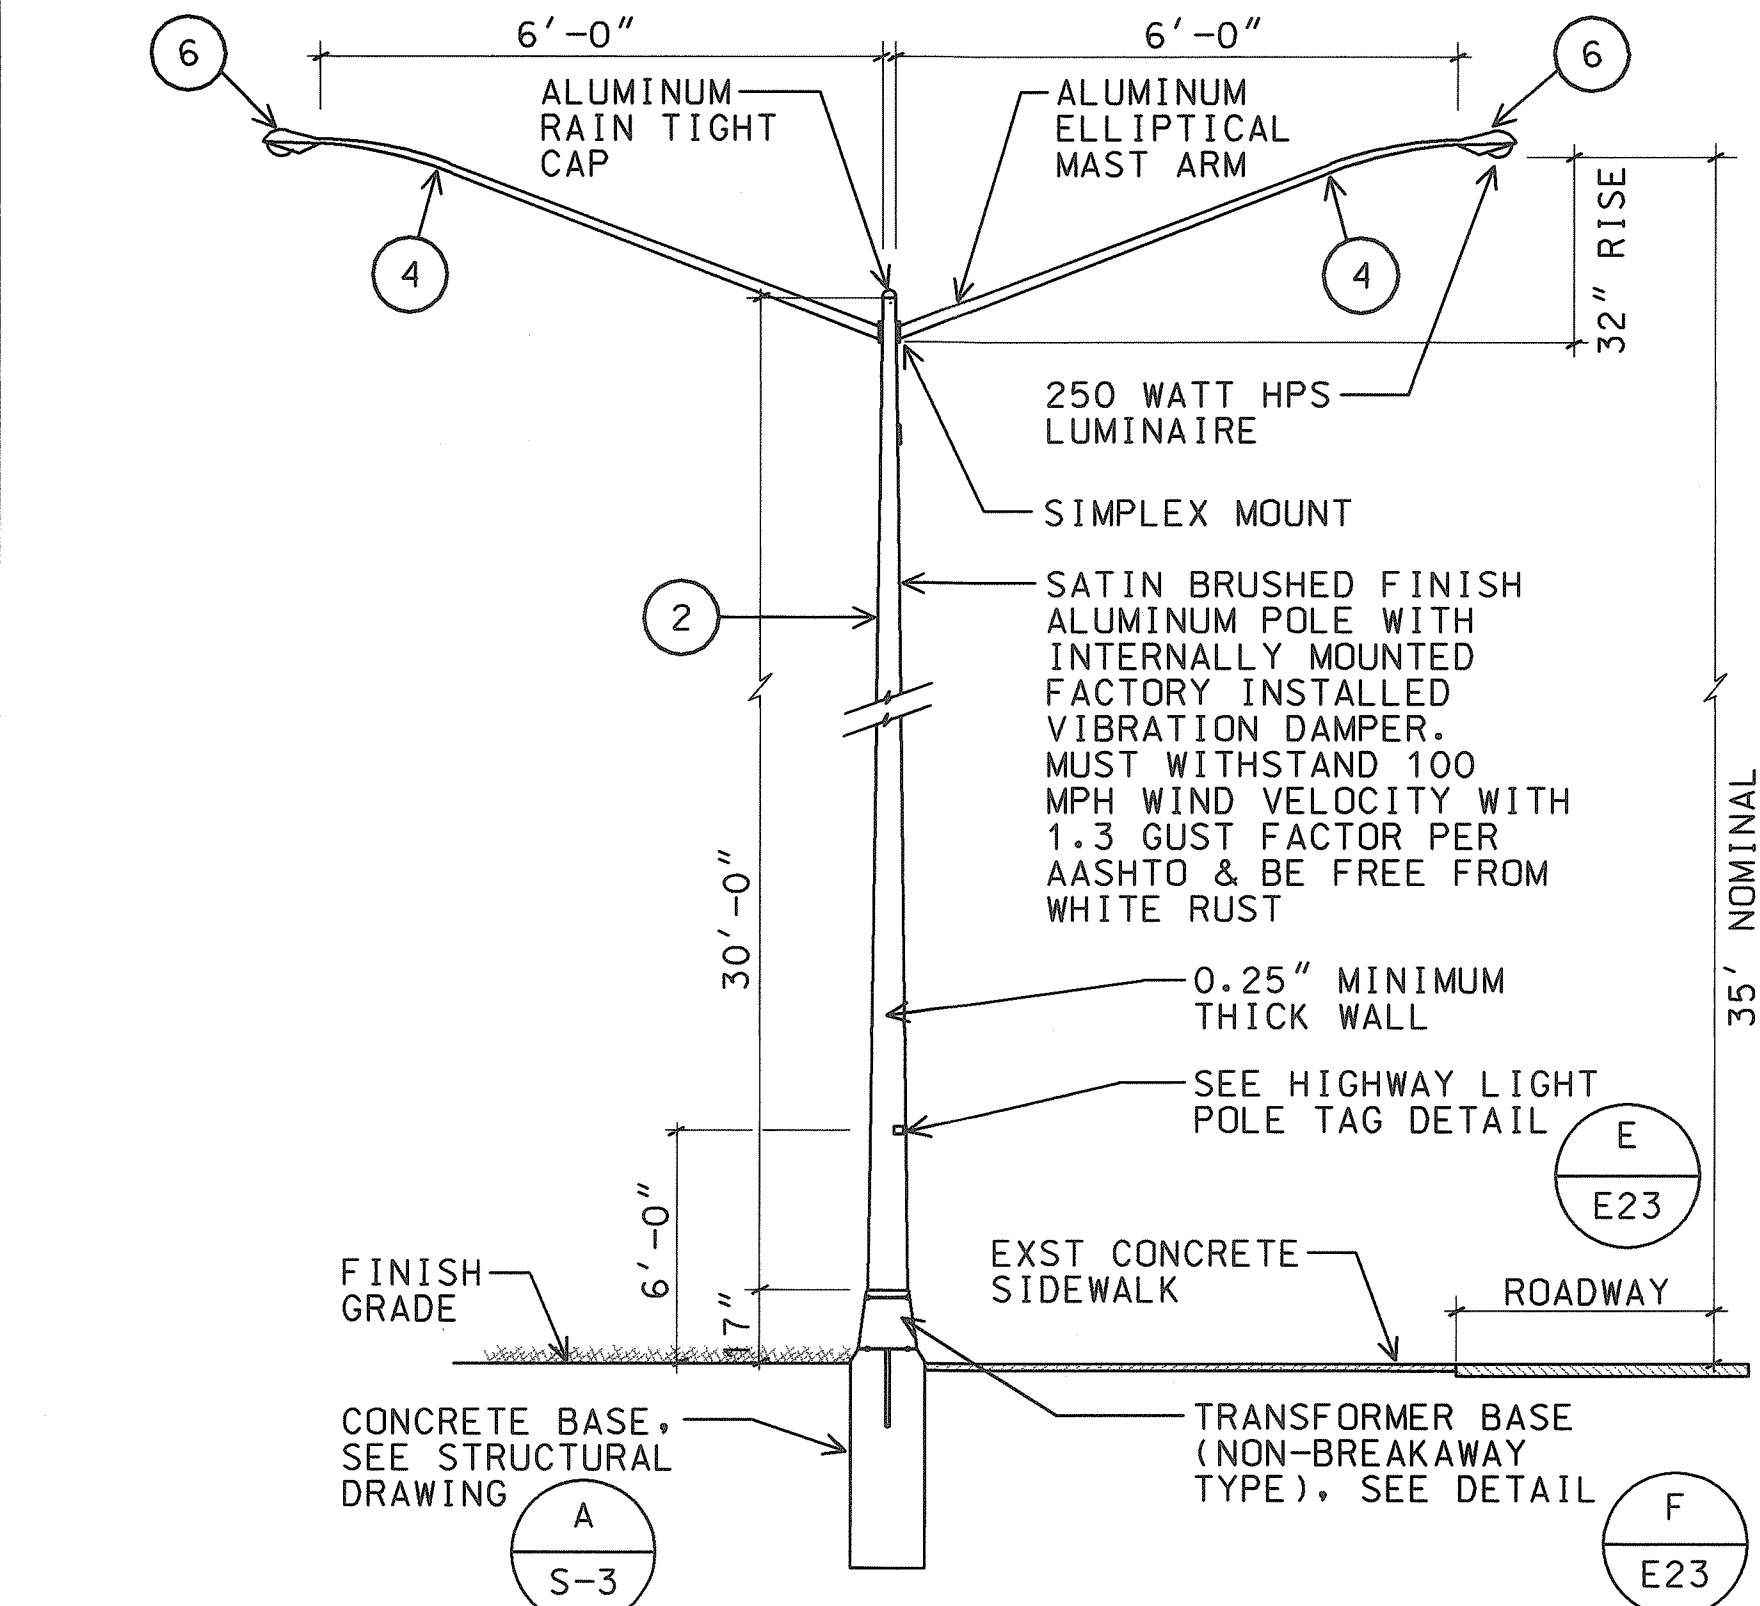


A STREET LIGHT STANDARD INSTALLATION BASE
E29 NTS 98058FDA

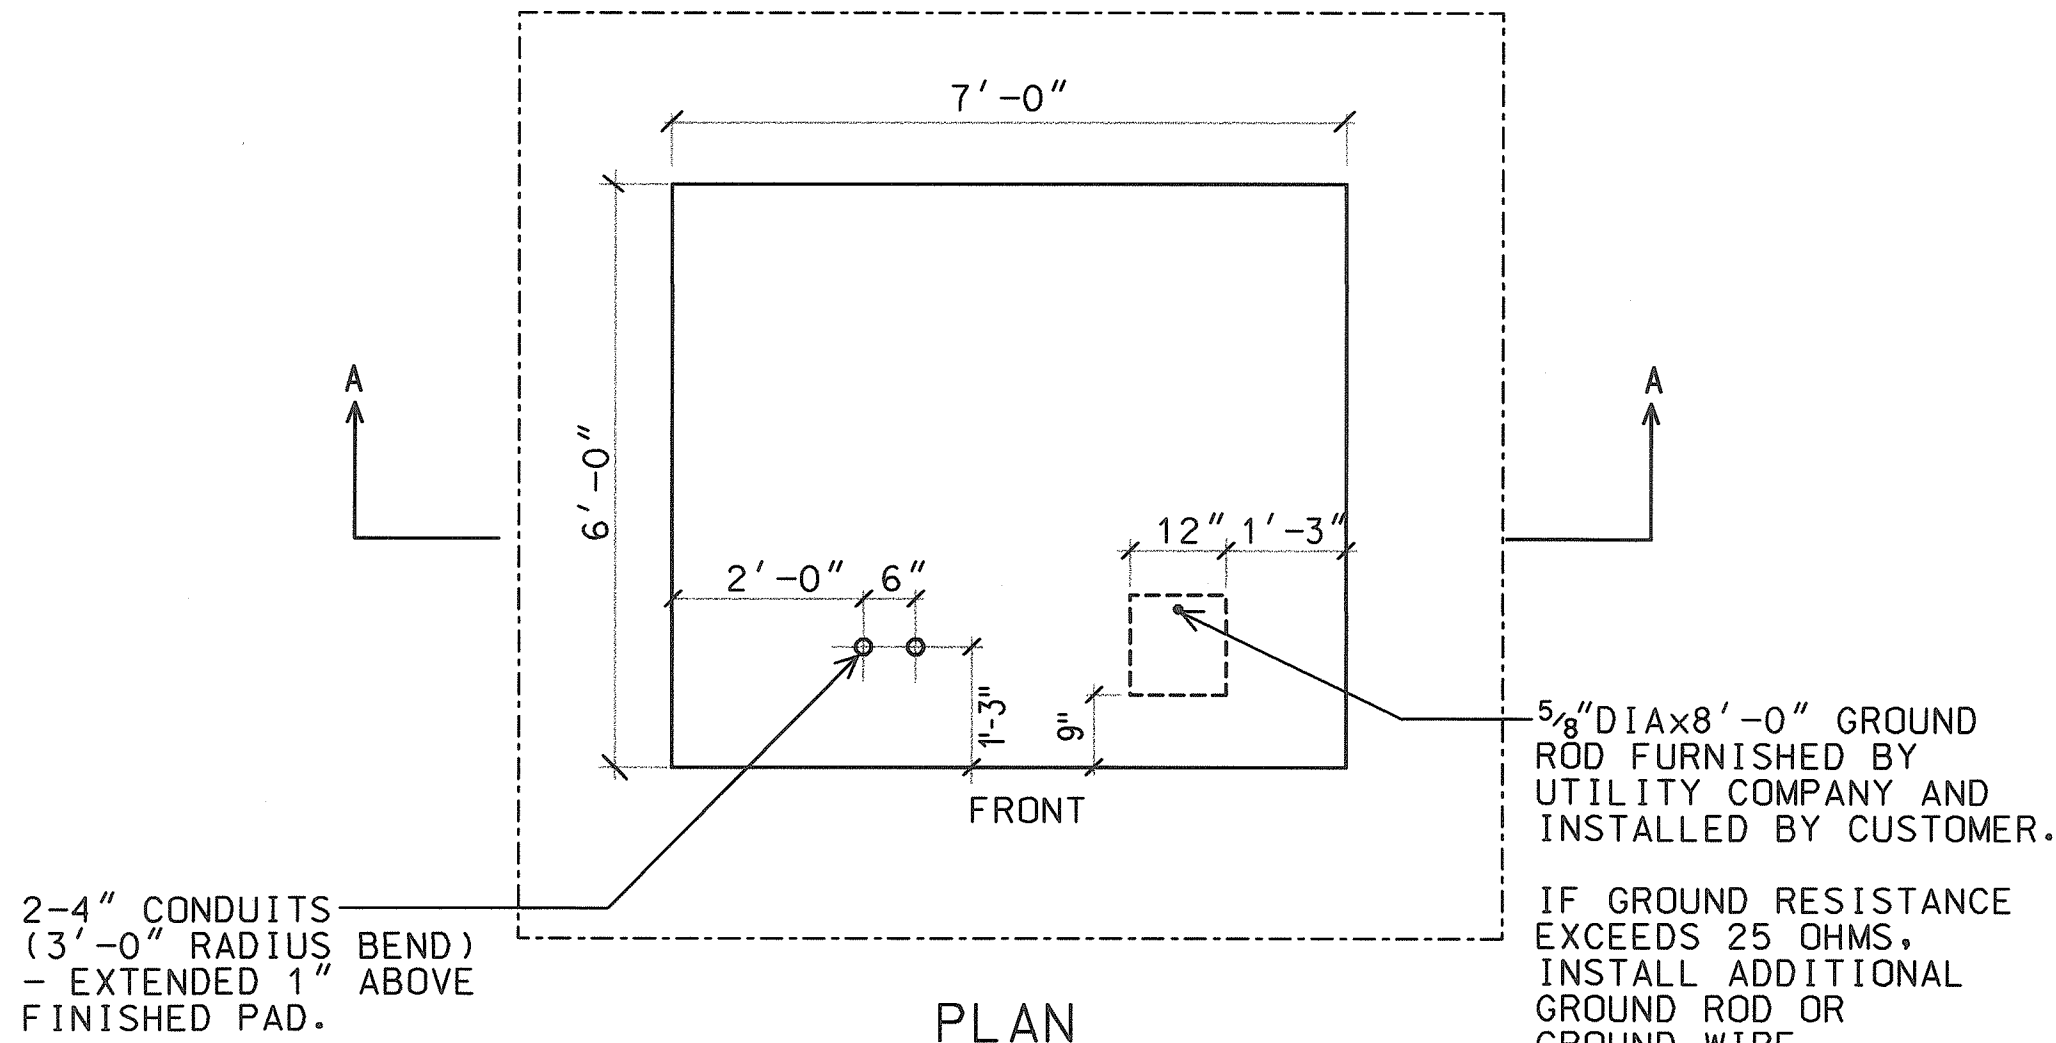

B 3PH TRANSFORMER PAD DETAIL
E29 SCALE: 1/2" = 1'-0" 98058FDB

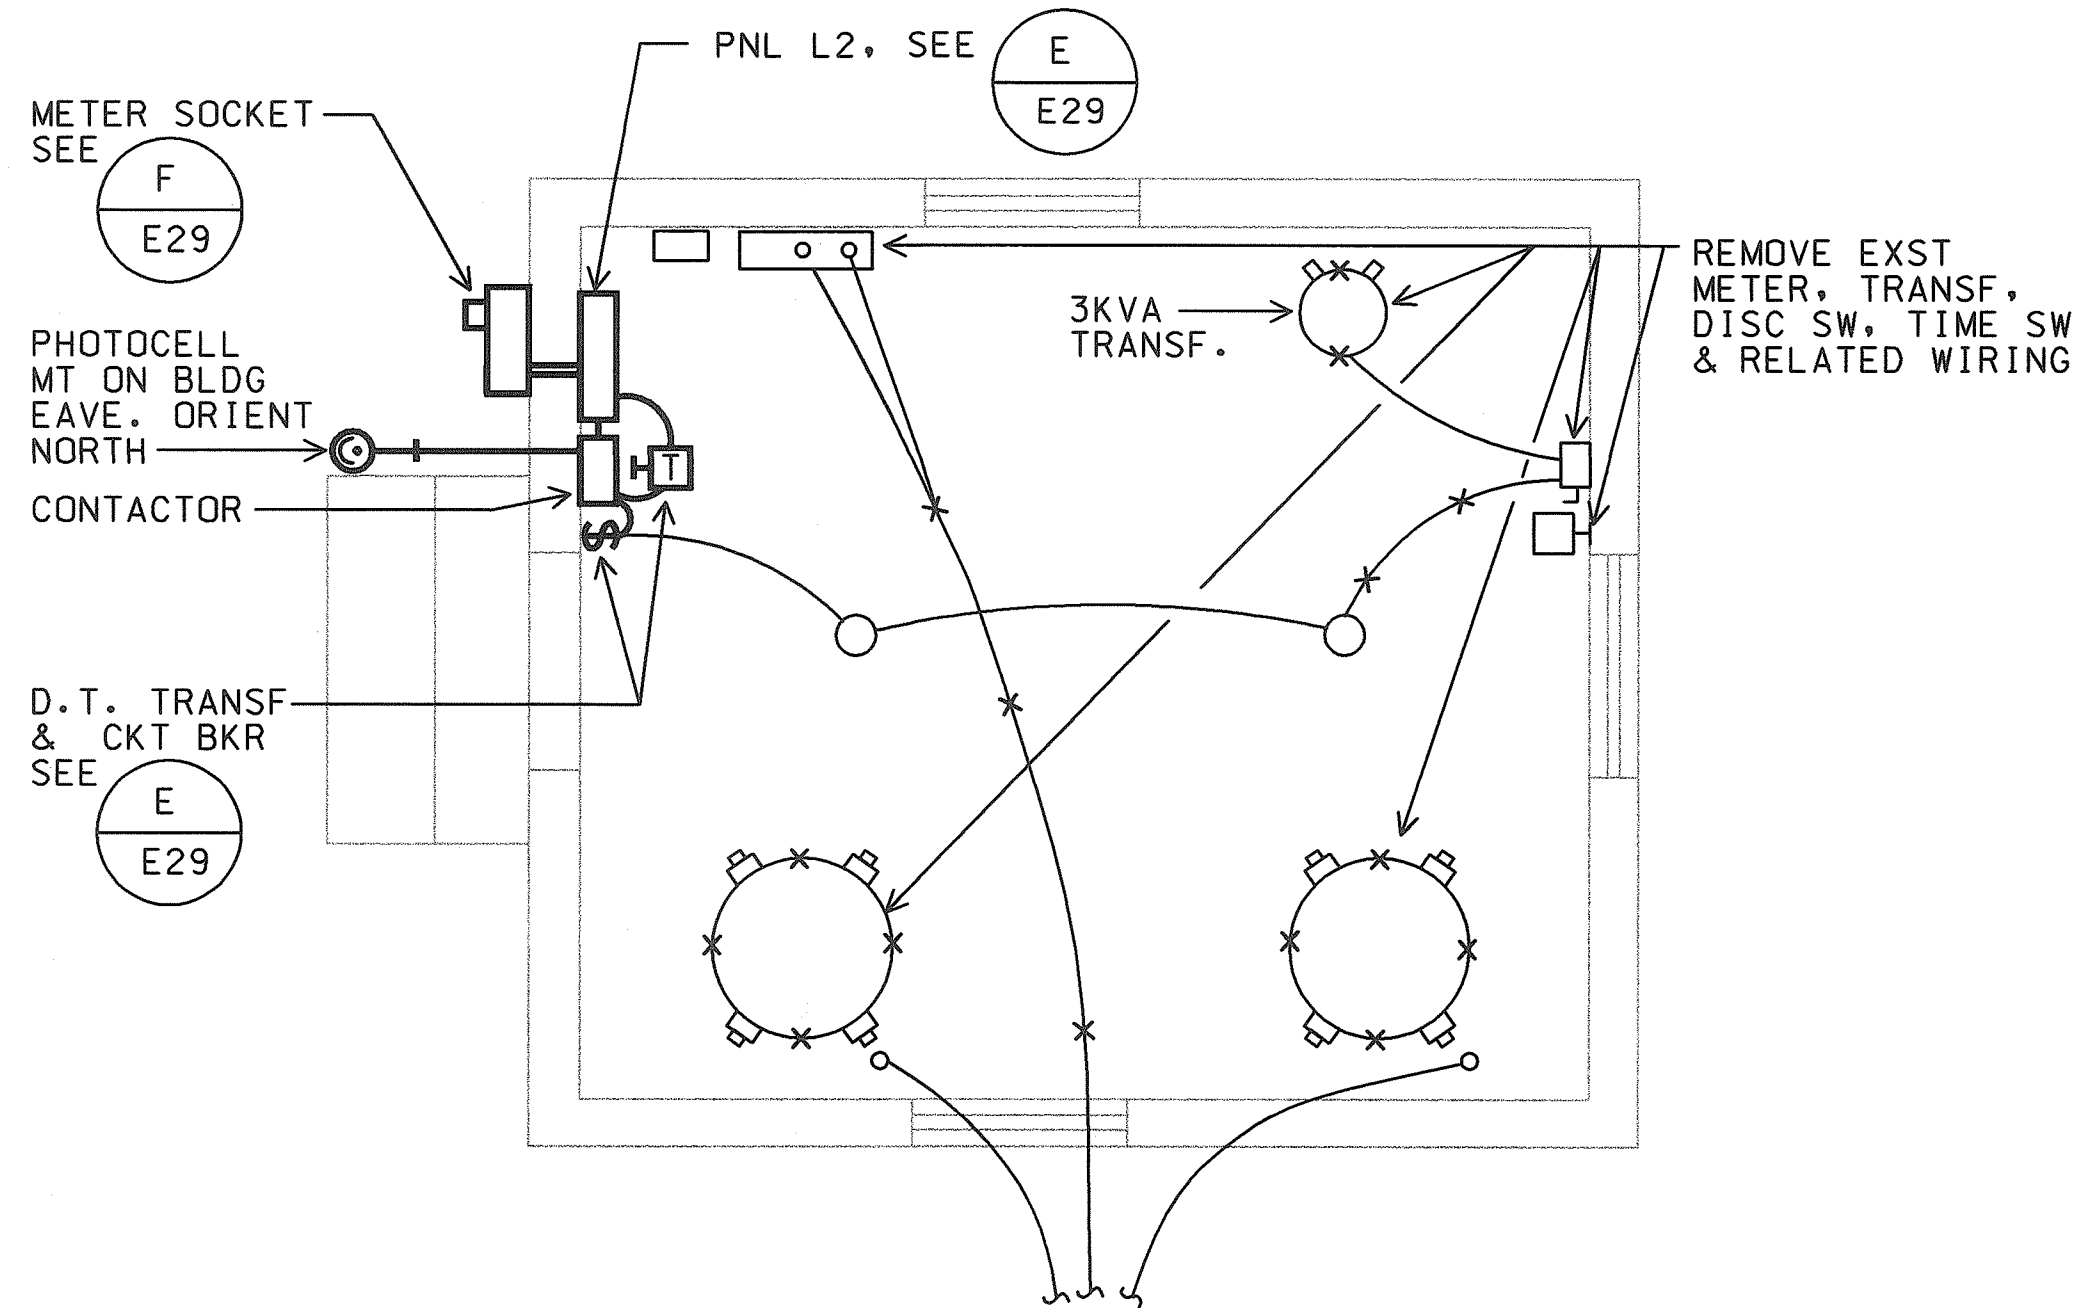


C SUBSTATION ELECTRICAL PLAN
E29 SCALE: 3/8" = 1'-0" 98058-FC

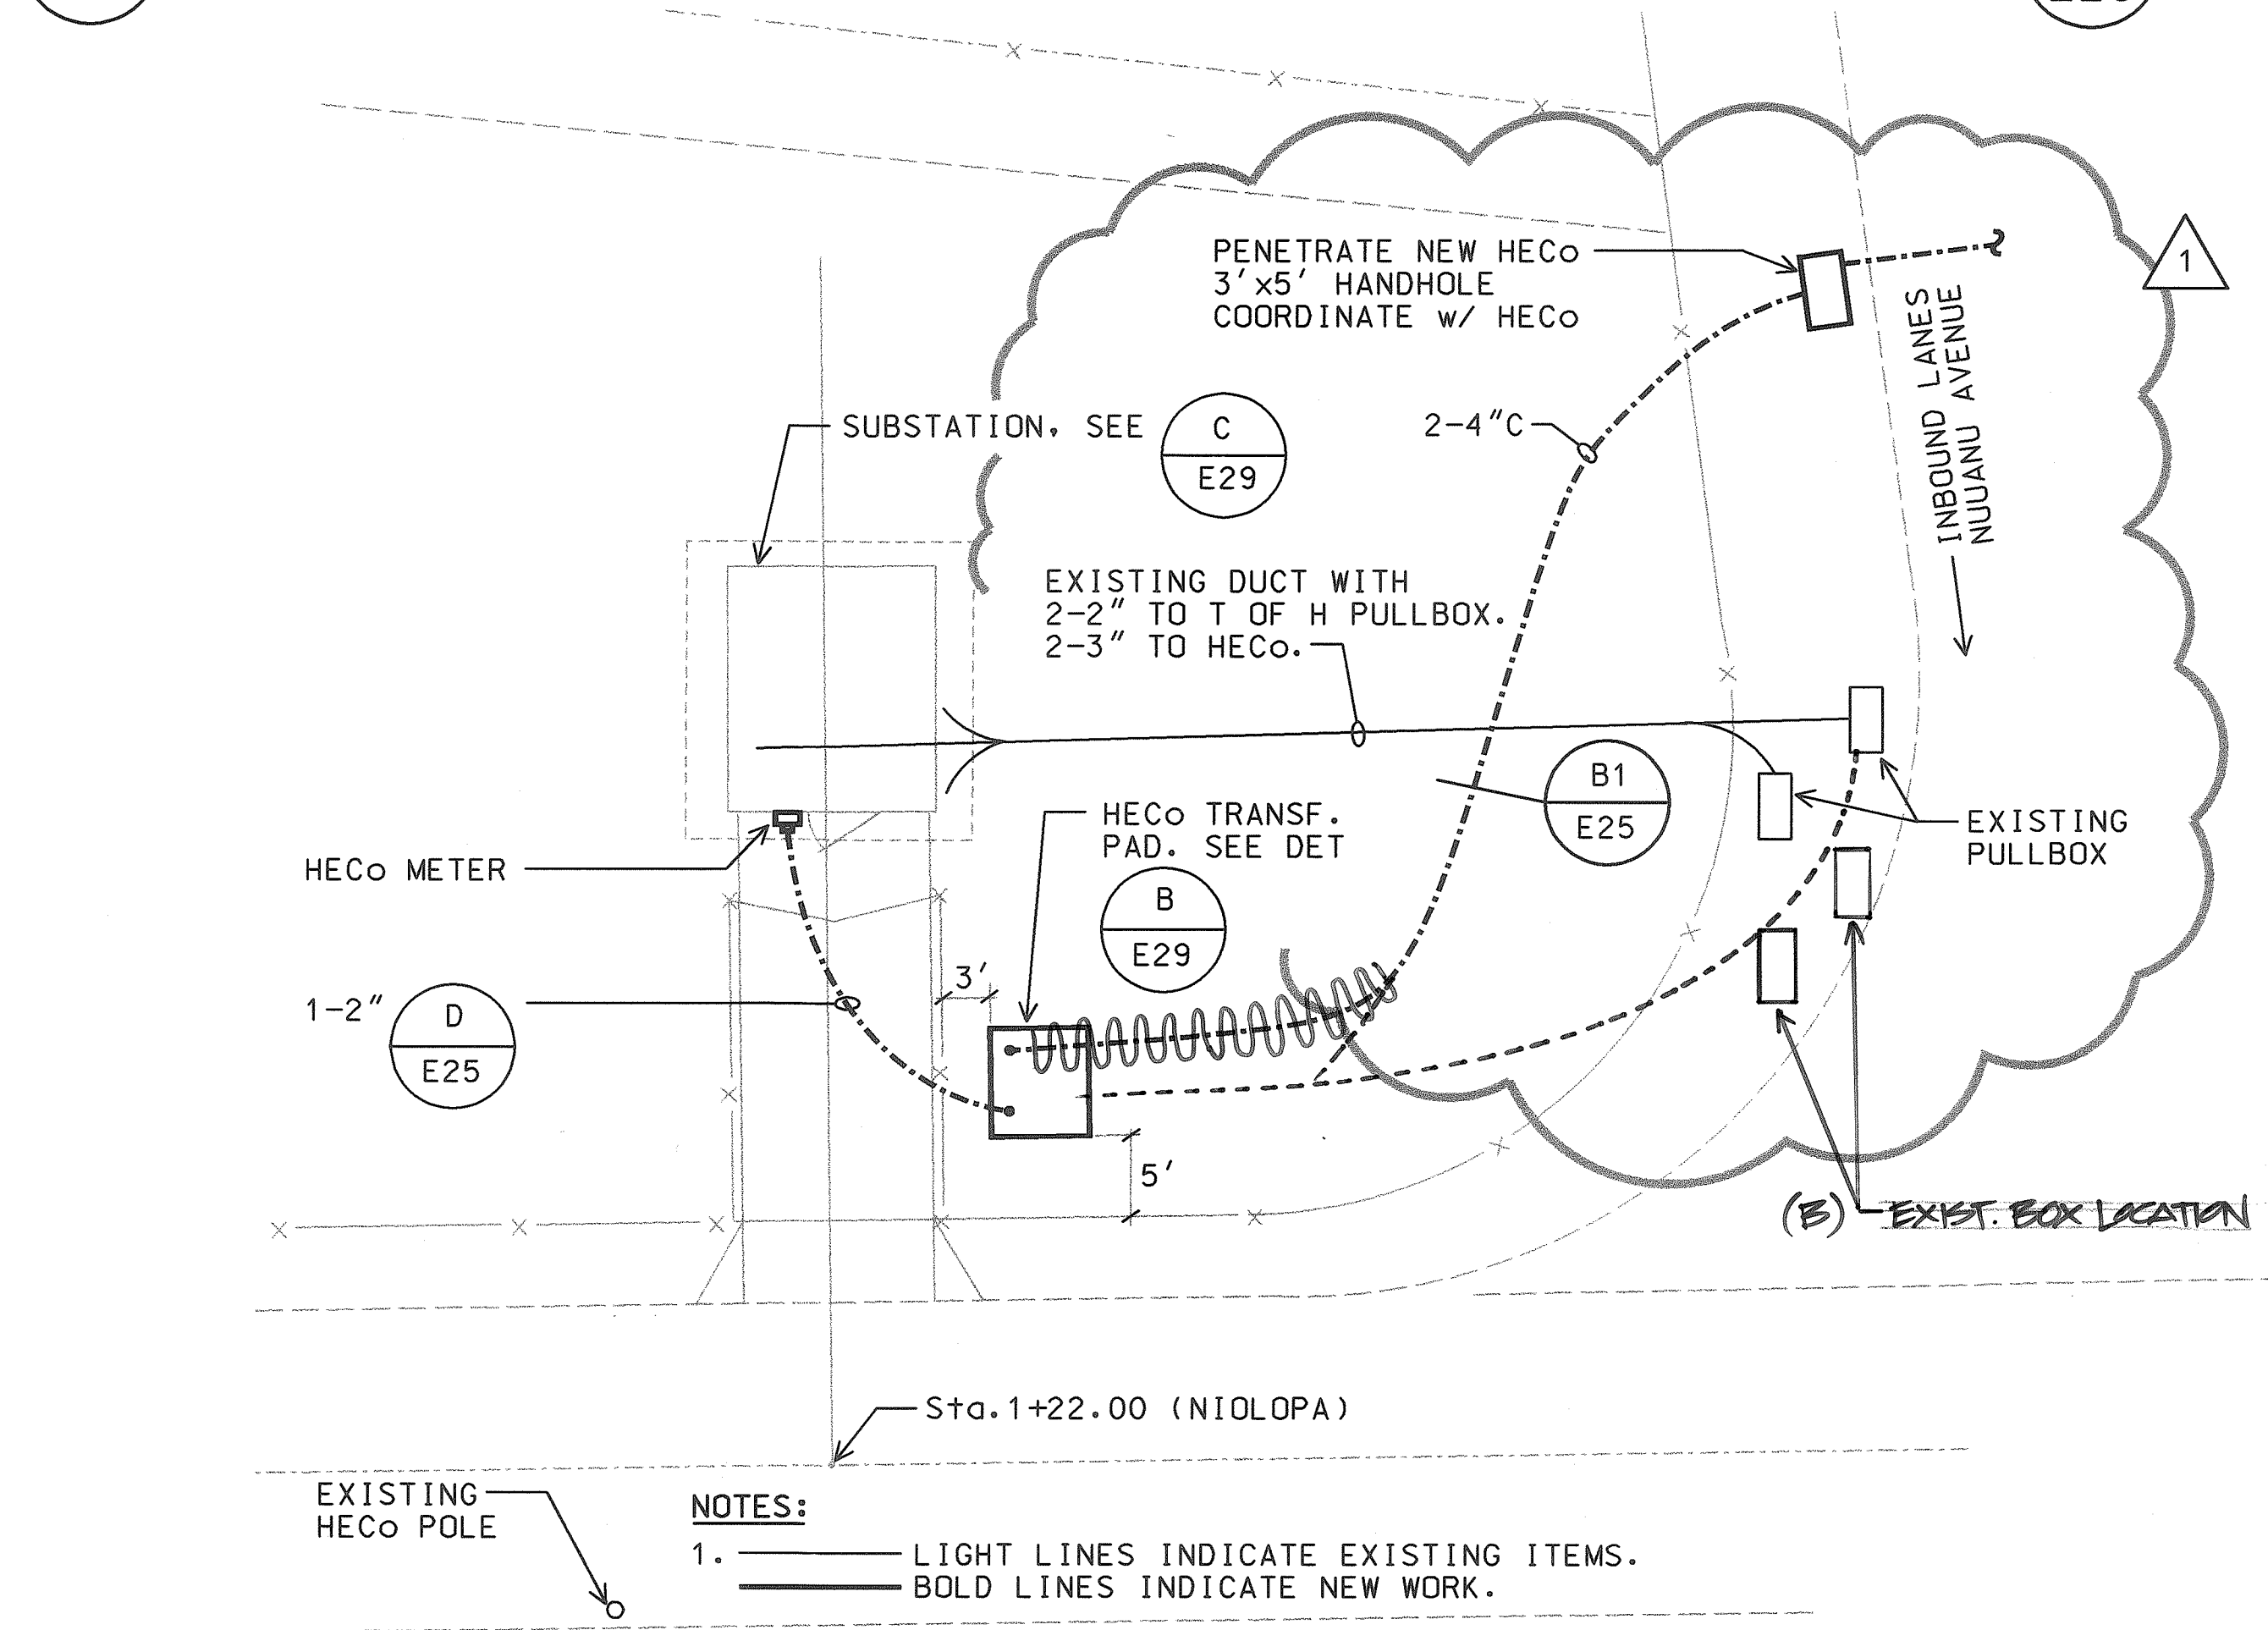


NOTES:
1. LIGHT LINES INDICATE EXISTING ITEMS.
BOLD LINES INDICATE NEW WORK.


D SITE ELECTRICAL PLAN
E29 SCALE: 1" = 10'-0" 98058-FD

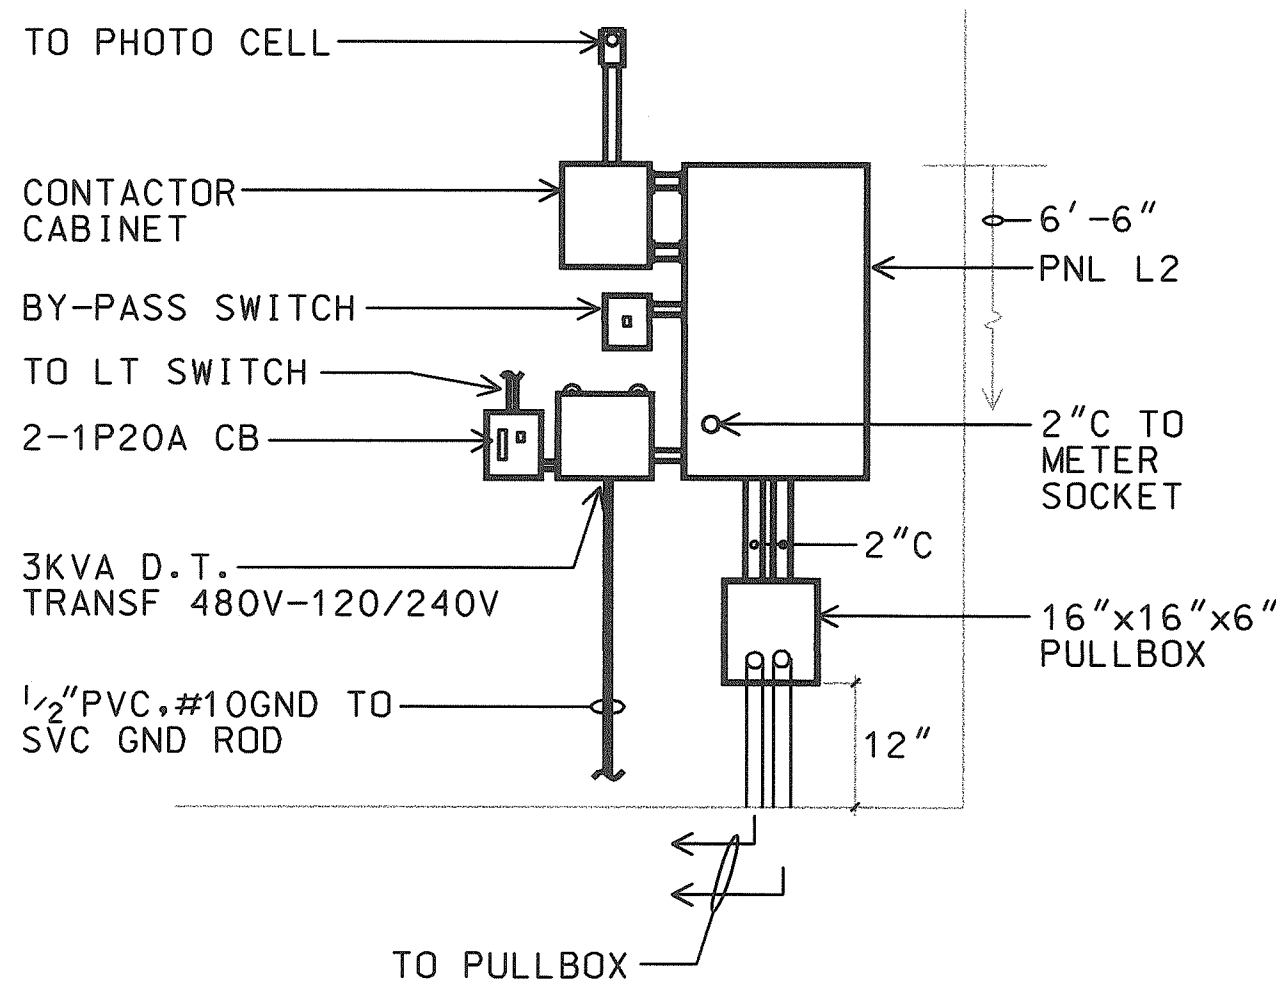

E ELEC APPARATUS ELEVATION
E29 NTS 98058FDE

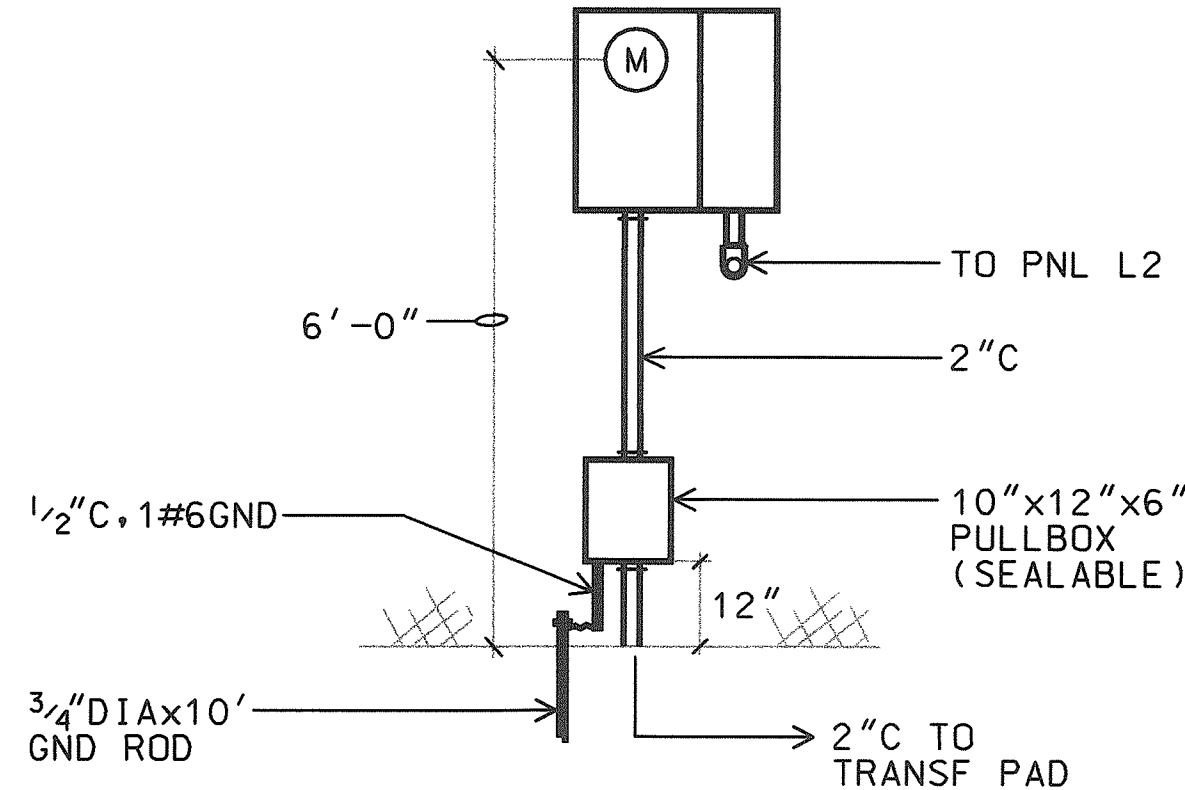

F SERVICE EQUIPMENT ELEVATION
E29 N.T.S. 98058FDF

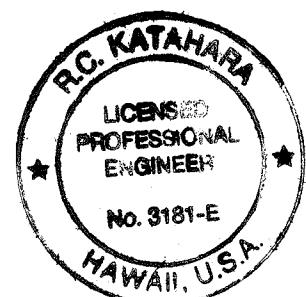


AS-BUILT
2/4/03


THIS WORK WAS PREPARED BY:
OR UNDER MY SUPERVISION.
R. KATAHARA 2/20/03
MK ENGINEERS, LTD.

DATE	REV	DESCRIPTION
12/17/99	1	REV. LOCATION OF HANDHOLE & DUCTLINE
STATE OF HAWAII DEPARTMENT OF TRANSPORTATION HIGHWAYS DIVISION		
SUBSTATION PLANS & DETAILS		
HIGHWAY LIGHTING SAFETY IMPROVEMENTS PALI HIGHWAY VICINITY OF WYLLIE INTERCHANGE TO JACK LANE		
PROJECT NO. STP-0300(66)		
SCALE: AS NOTED DATE: OCTOBER 1998		
SHEET No. E29 OF 56 SHEETS		


FED. ROAD DIST. NO.	STATE	FED. AID PROJ. NO.	FISCAL YEAR	SHEET NO.	TOTAL SHEETS
HAWAII	HAW.	STP-0300(66)	1998		

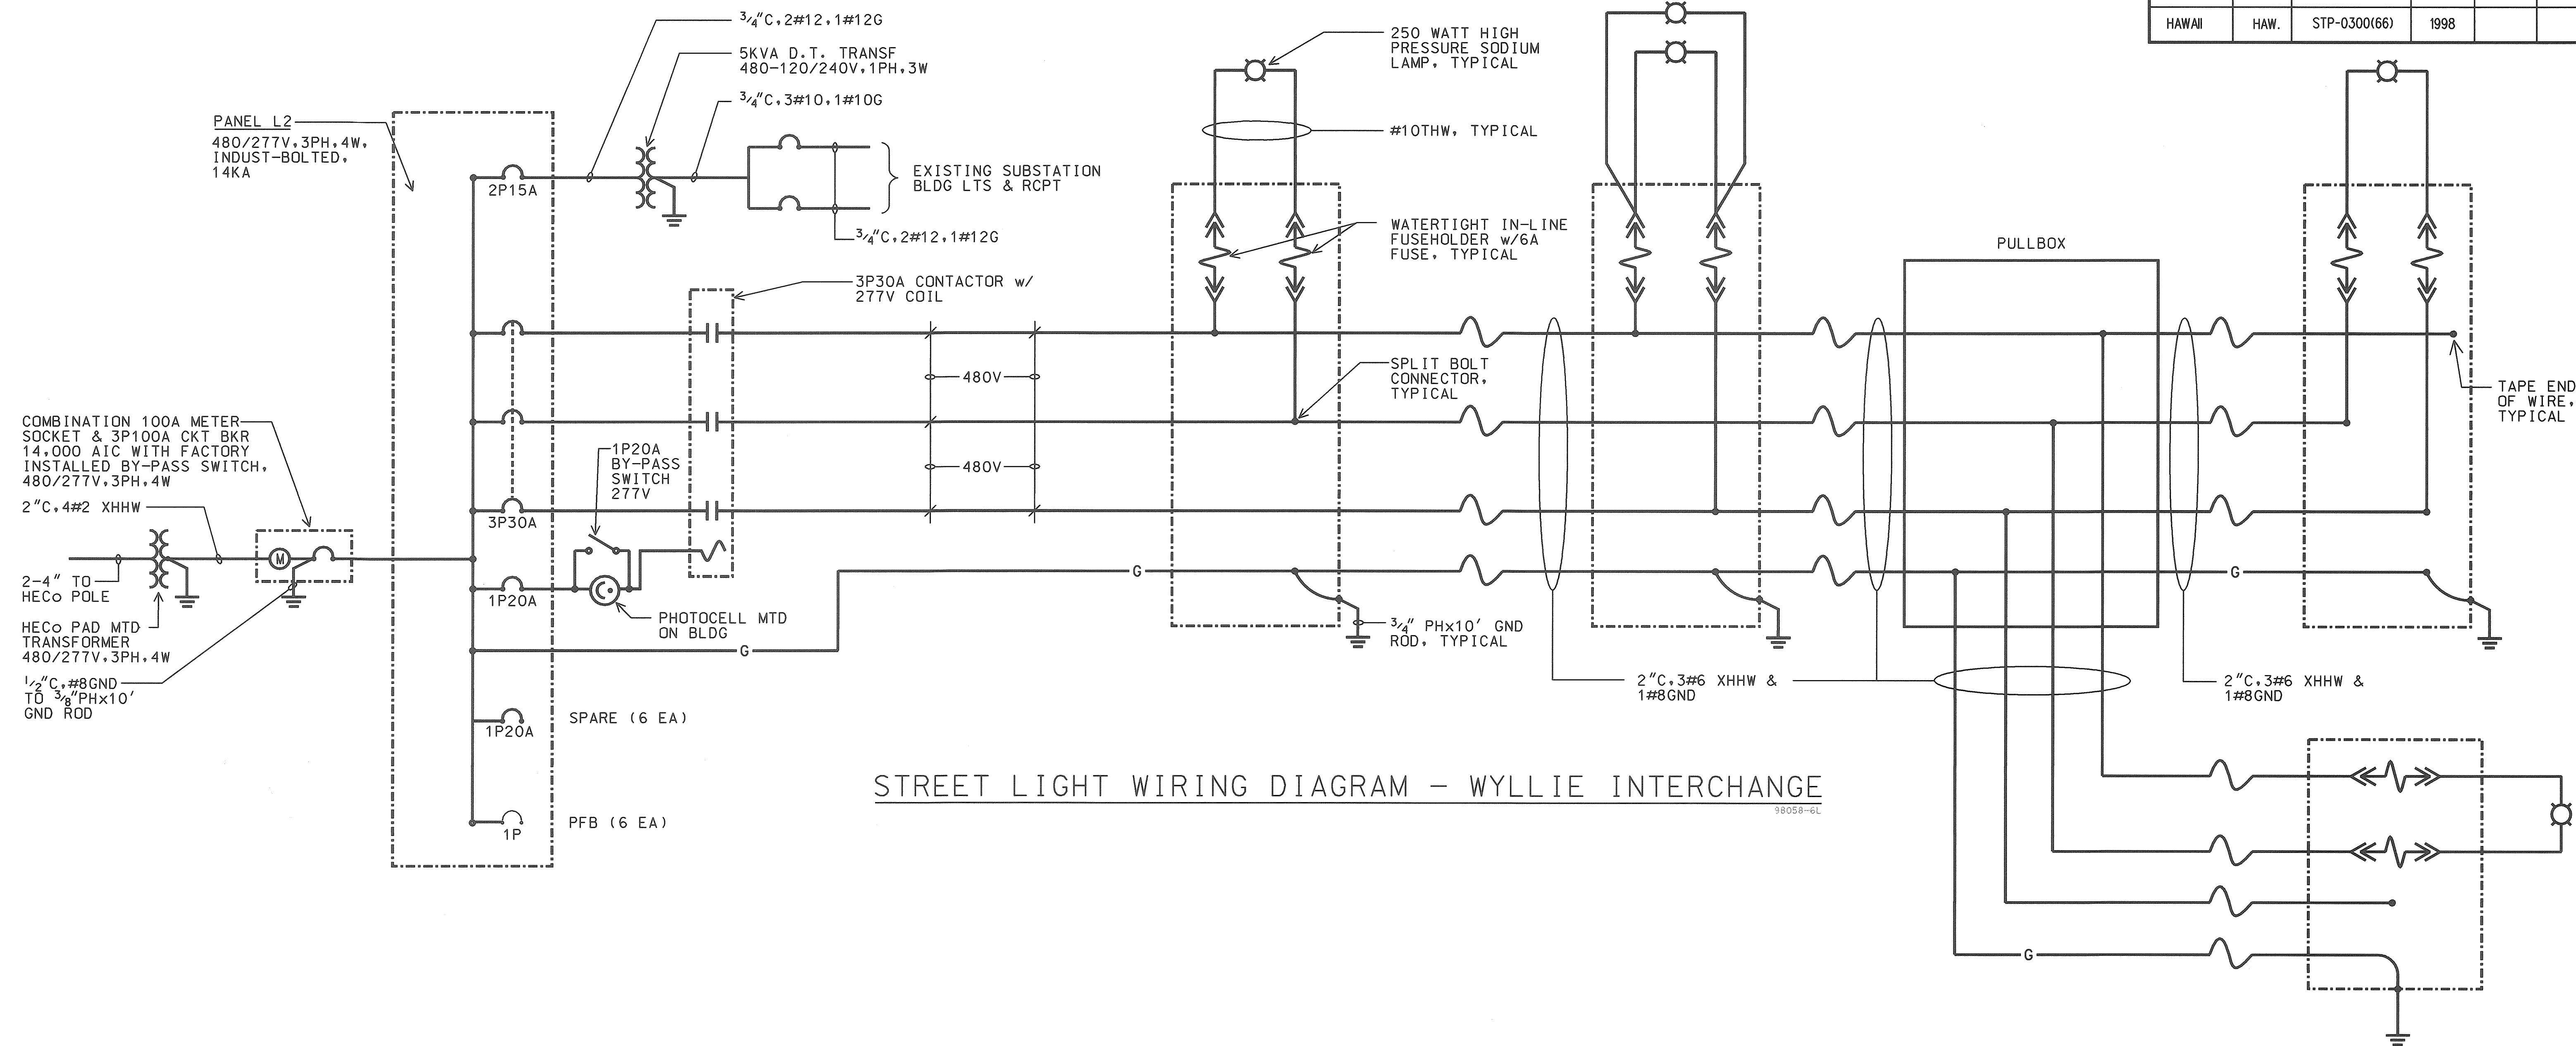

STREET LIGHT WIRING DIAGRAM - WYLLIE INTERCHANGE

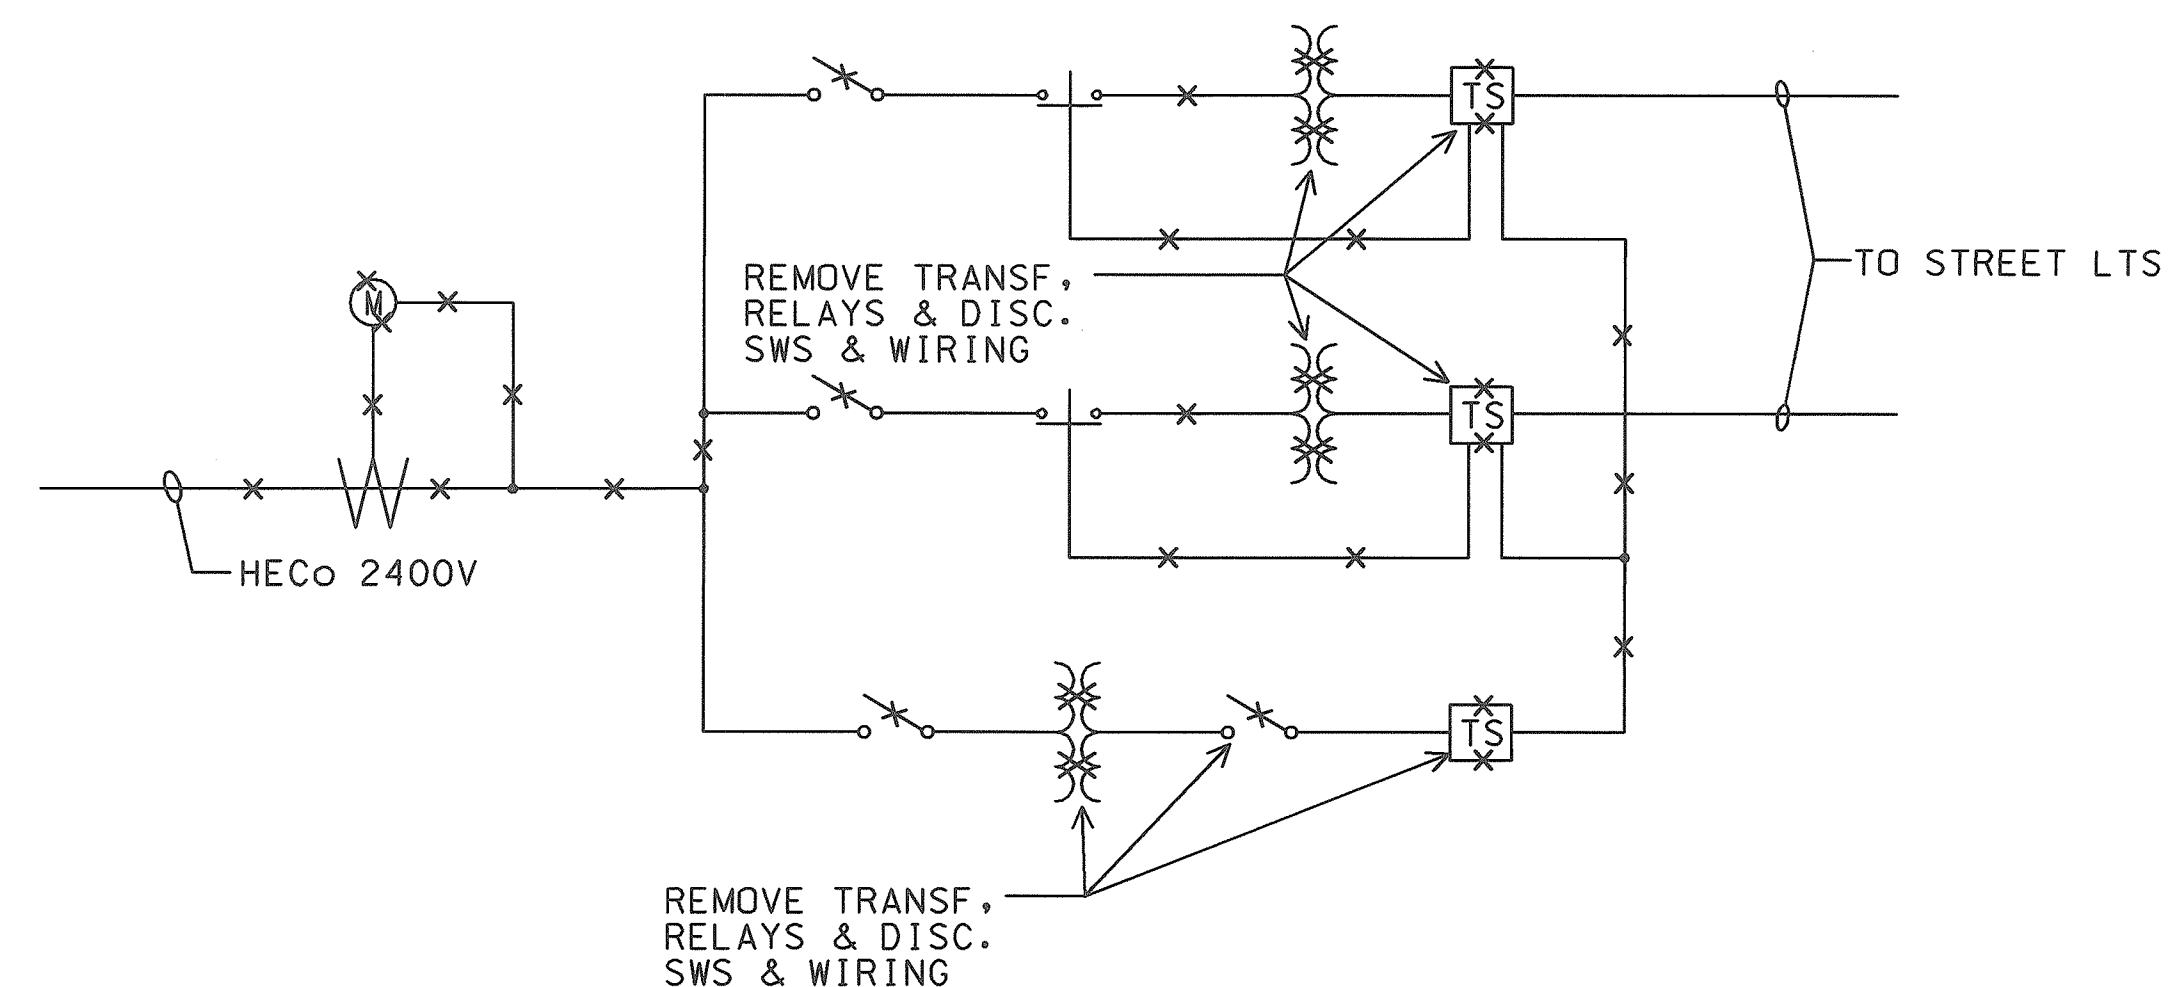

DEMOLITION SERIES CIRCUIT ONE-LINE DIAGRAM

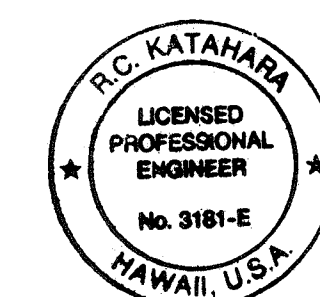

THIS WORK WAS PREPARED BY ME
OR UNDER MY SUPERVISION.
R.C. KATAHARA 2/25/98
R.K. ENGINEERS, LTD.

AS-BUILT

2/4/03

IMP

STATE OF HAWAII

DEPARTMENT OF TRANSPORTATION

HIGHWAYS DIVISION

WIRING DIAGRAM

HIGHWAY LIGHTING SAFETY IMPROVEMENTS

PALI HIGHWAY

VICINITY OF WYLLIE INTERCHANGE TO JACK LANE


PROJECT NO. STP-0300(66)

SCALE: AS NOTED

DATE: OCTOBER 1998


SHEET No. 30 OF 56 SHEETS

FED. ROAD DIST. NO.	STATE	FED. AID PROJ. NO.	FISCAL YEAR	SHEET NO.	TOTAL SHEETS
HAWAII	HAW.	STP-0300(66)	1998		

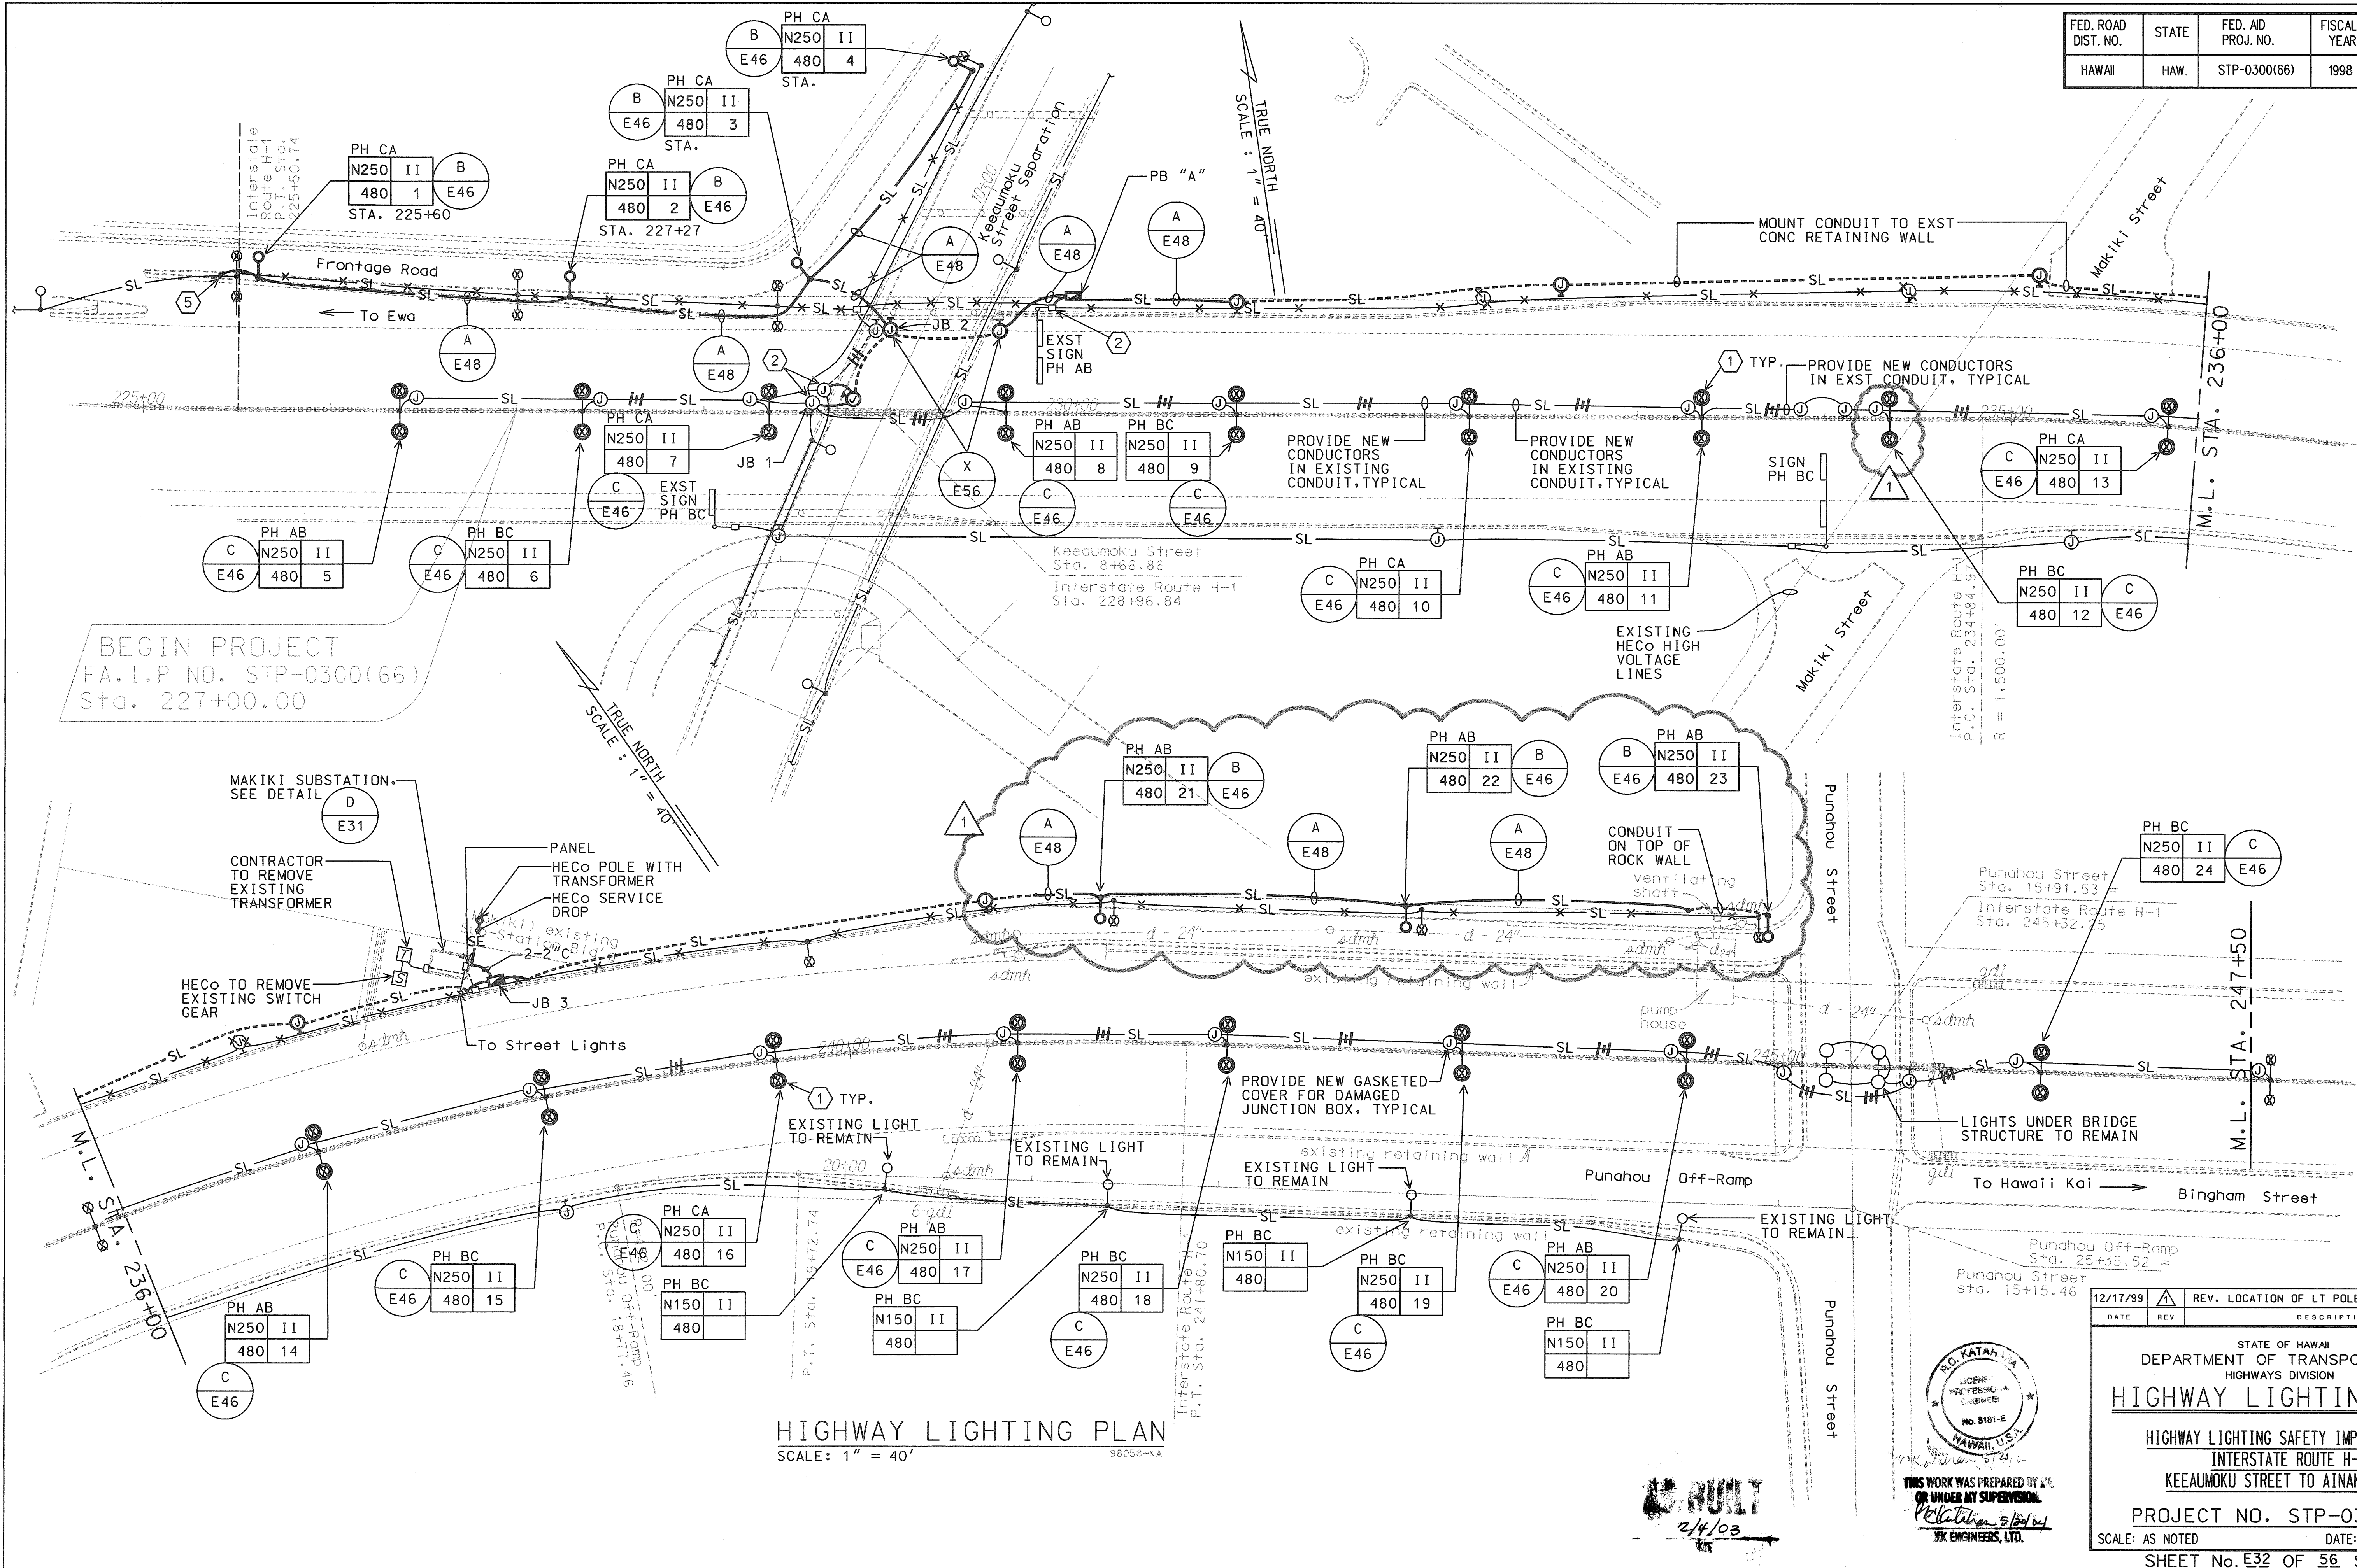

HIGHWAY LIGHTING PLAN
SCALE: 1" = 40'

98058-KA

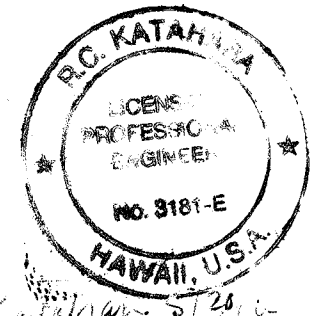


THIS WORK WAS PREPARED BY ME
OR UNDER MY SUPERVISION
DATE: 5/14/03
BY: [Signature]
FIRM: [Firm Name]


DATE	REV	DESCRIPTION
12/17/99	1	REV. LOCATION OF LT POLES

STATE OF HAWAII DEPARTMENT OF TRANSPORTATION HIGHWAYS DIVISION	
HIGHWAY LIGHTING PLAN	
HIGHWAY LIGHTING SAFETY IMPROVEMENTS INTERSTATE ROUTE H-1 KEEAUMOKU STREET TO AINALOA AVE	
PROJECT NO. STP-0300(66)	
SCALE: AS NOTED	DATE: JANUARY 1999
SHEET No. 52 OF 56 SHEETS	


FED. ROAD DIST. NO.	STATE	FED. AID PROJ. NO.	FISCAL YEAR	SHEET NO.	TOTAL SHEETS
HAWAII	HAW.	STP-0300(66)	1998		

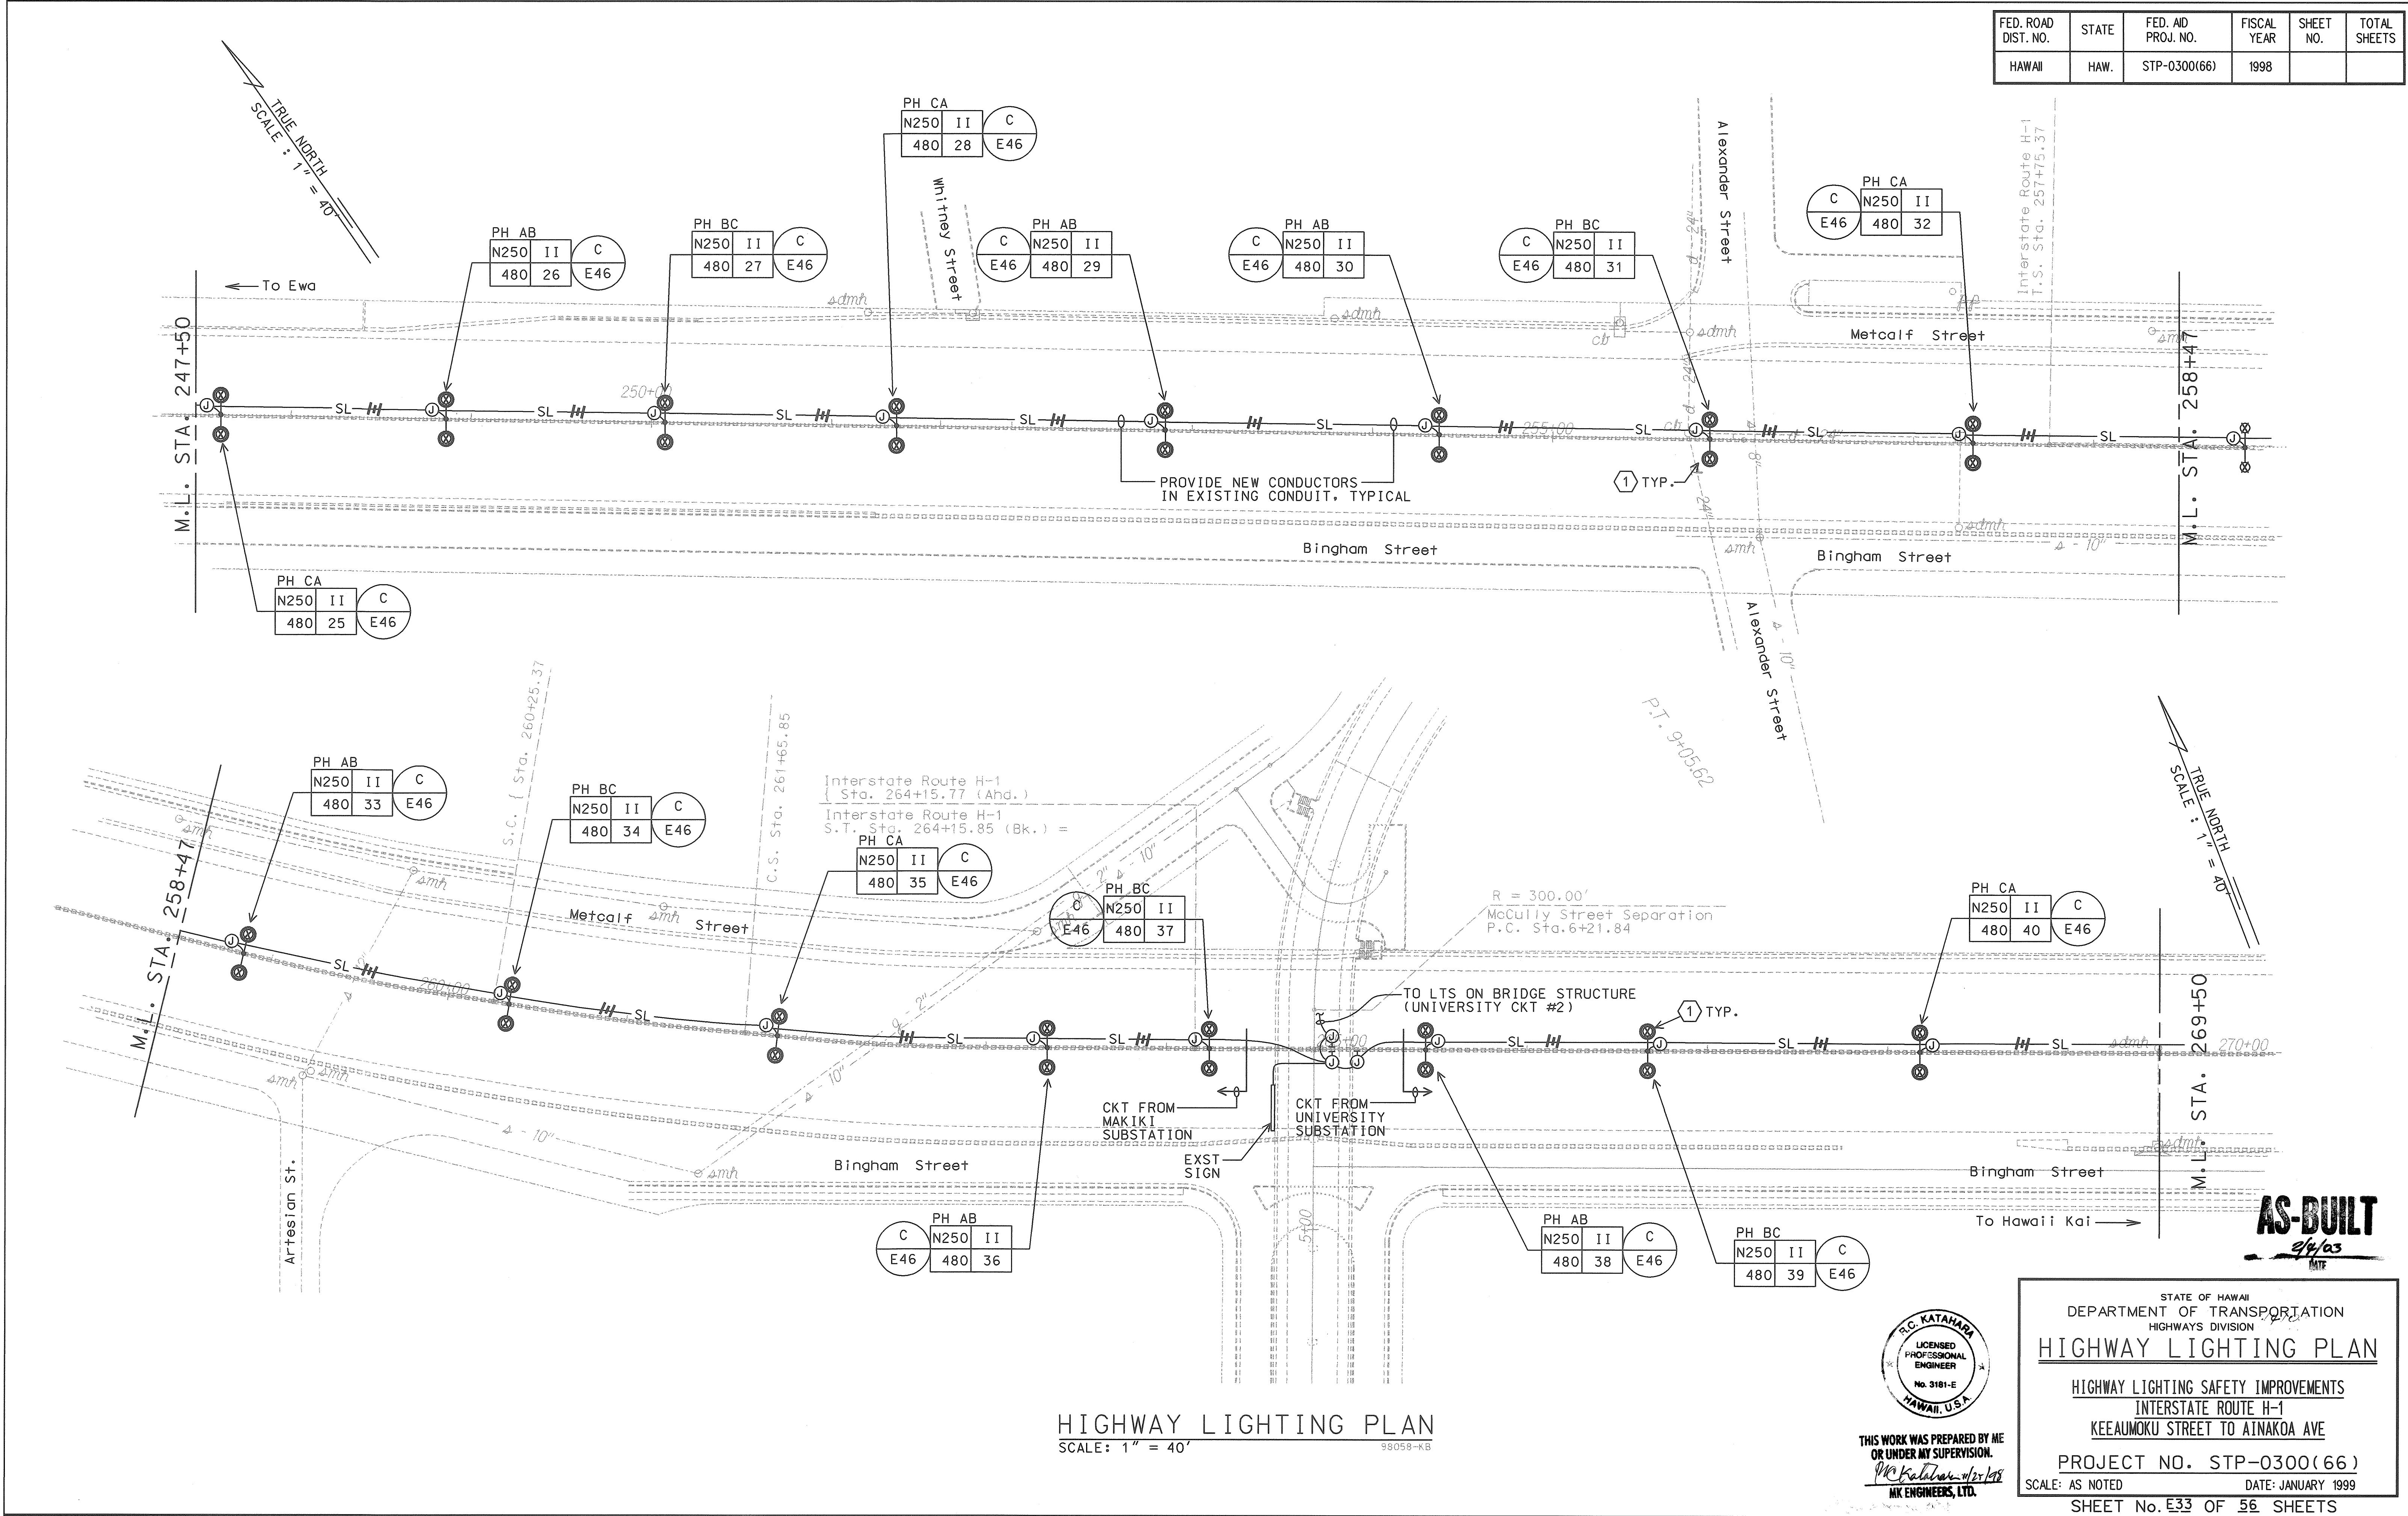

FED. ROAD DIST. NO.	STATE	FED. AID PROJ. NO.	FISCAL YEAR	SHEET NO.	TOTAL SHEETS
HAWAII	HAW.	STP-0300(66)	1998		

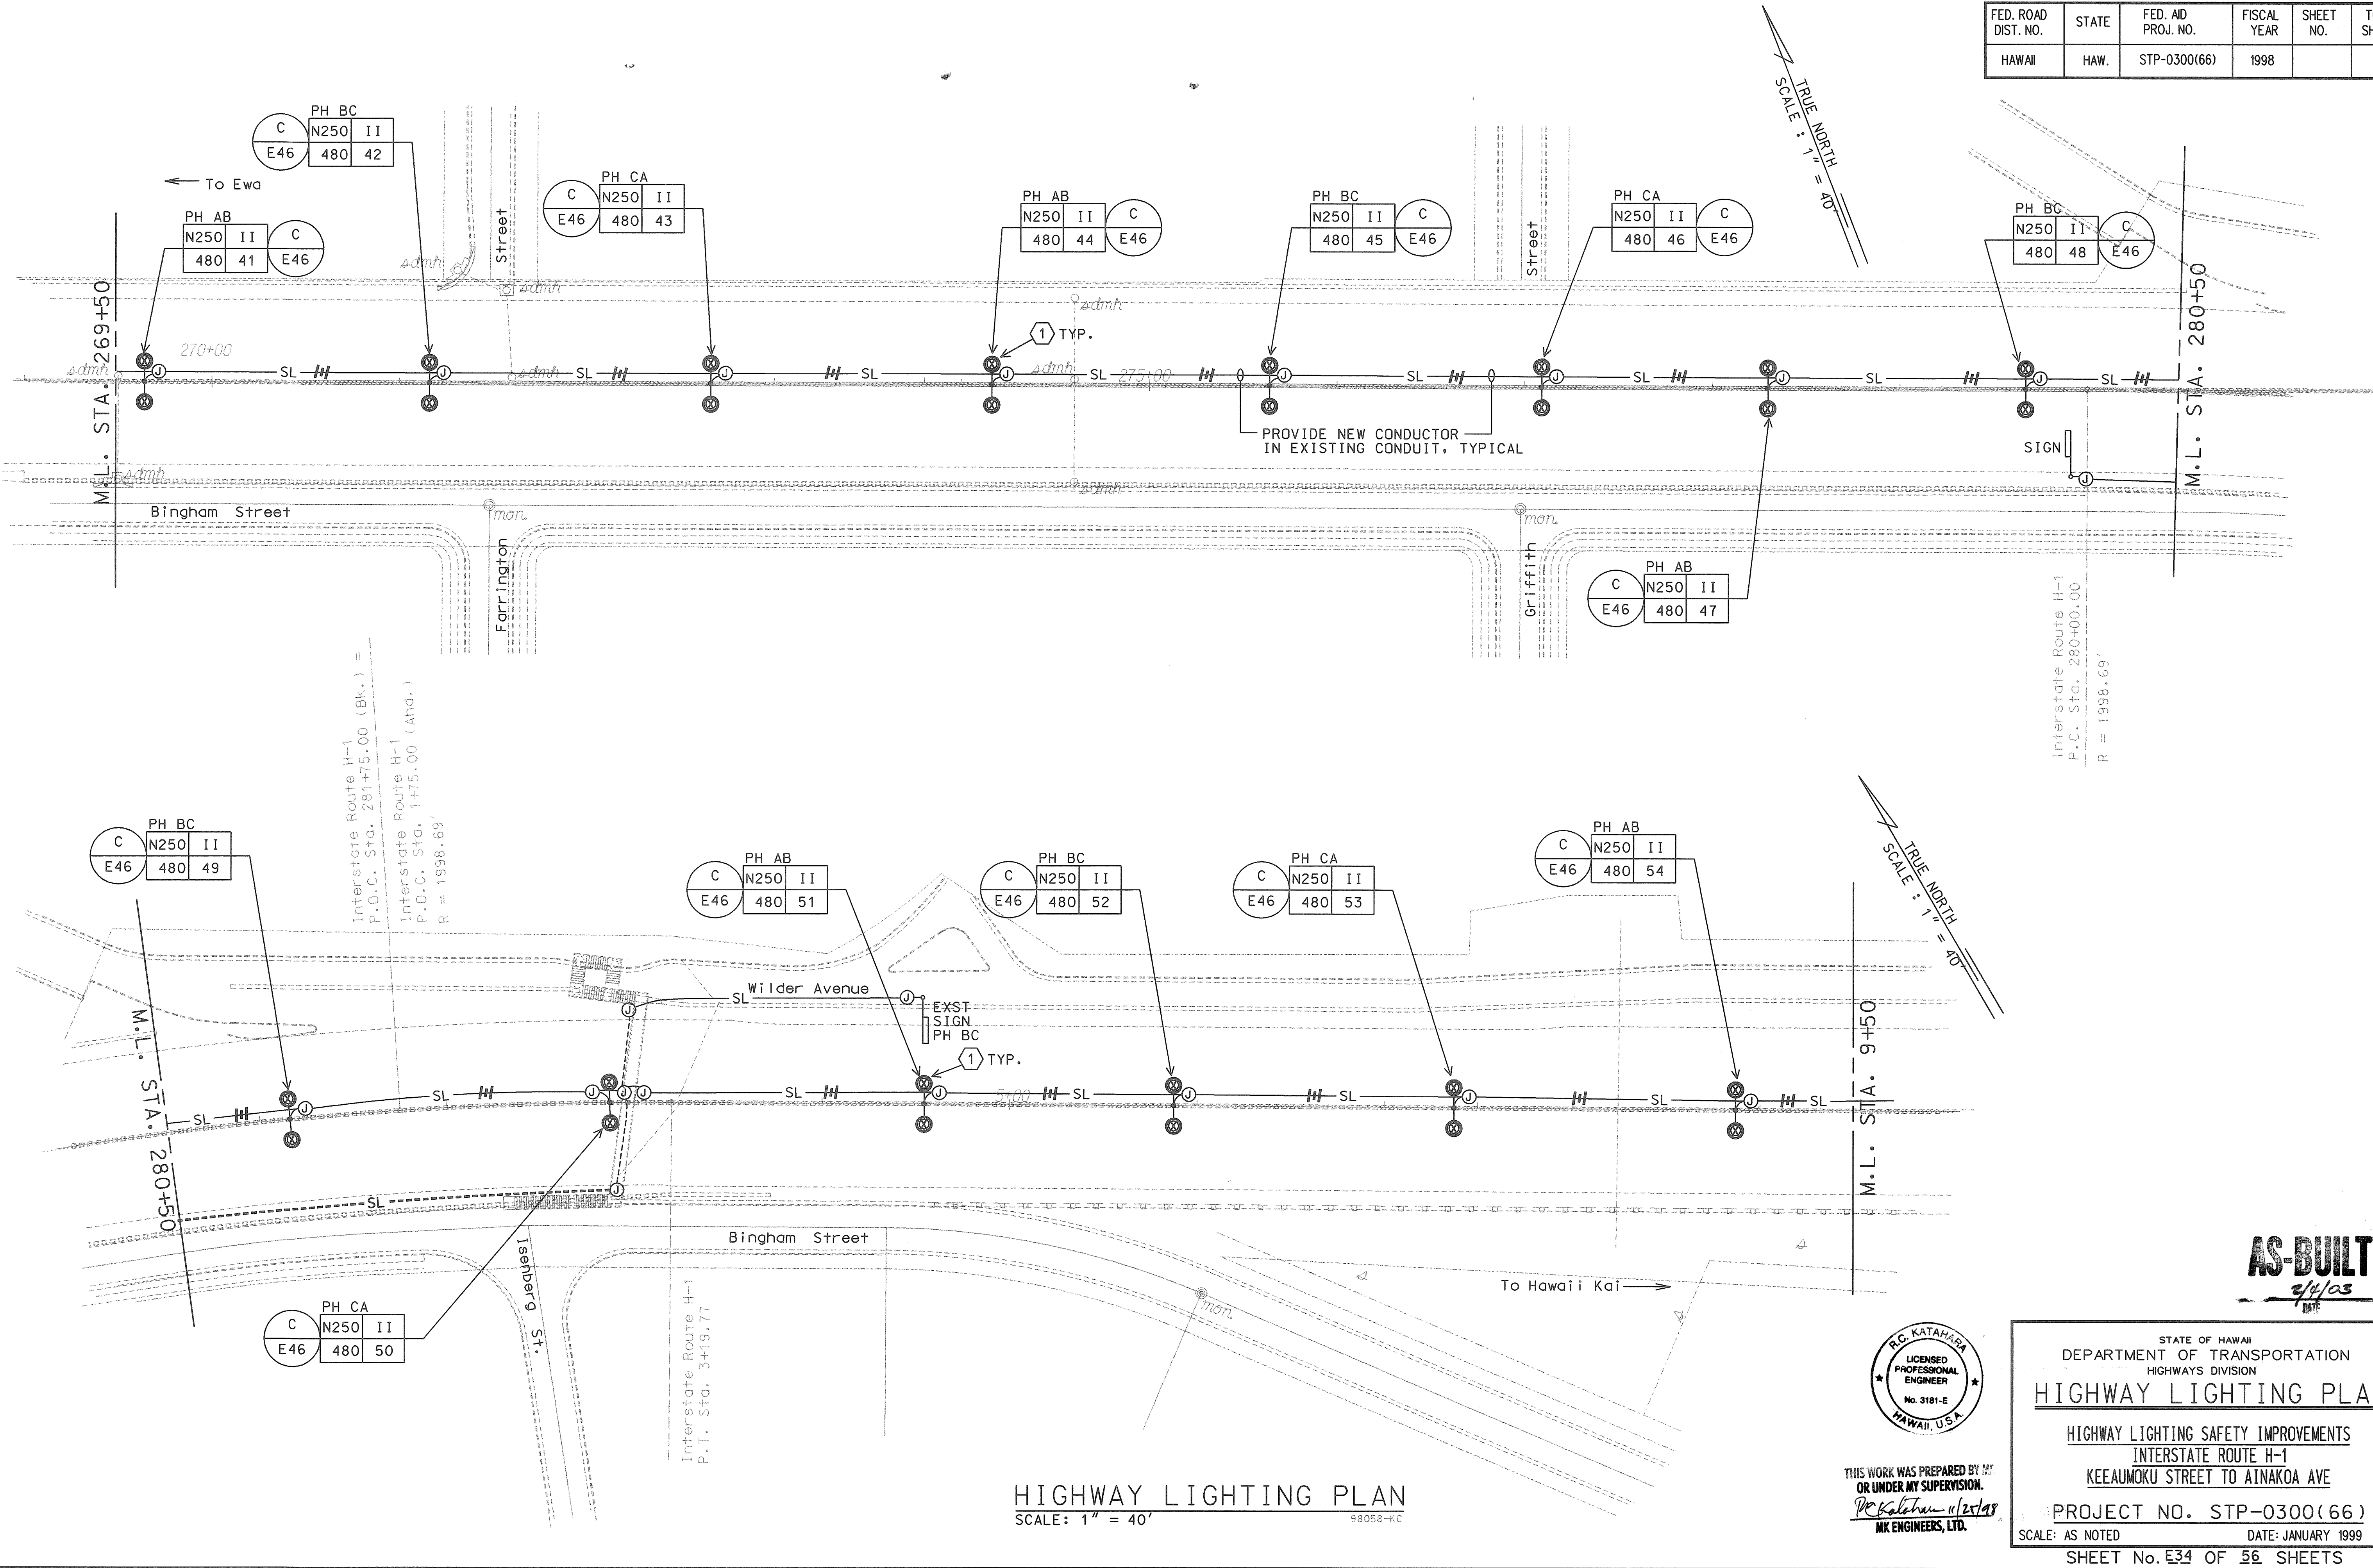

HIGHWAY LIGHTING PLAN
SCALE: 1" = 40'

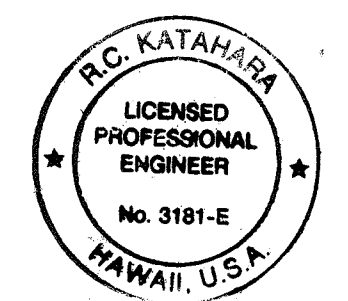


THIS WORK WAS PREPARED BY ME,
OR UNDER MY SUPERVISION.
R. C. KATAHARA 11/25/98
MK ENGINEERS, LTD.

AS-BUILT
2/4/03


STATE OF HAWAII
DEPARTMENT OF TRANSPORTATION
HIGHWAYS DIVISION
HIGHWAY LIGHTING PLAN
HIGHWAY LIGHTING SAFETY IMPROVEMENTS
INTERSTATE ROUTE H-1
KEEAUMOKU STREET TO AINAKOA AVE
PROJECT NO. STP-0300(66)
SCALE: AS NOTED DATE: JANUARY 1999
SHEET No. E34 OF 56 SHEETS

FED. ROAD DIST. NO.	STATE	FED. AID PROJ. NO.	FISCAL YEAR	SHEET NO.	TOTAL SHEETS
HAWAII	HAW.	STP-0300(66)	1998		

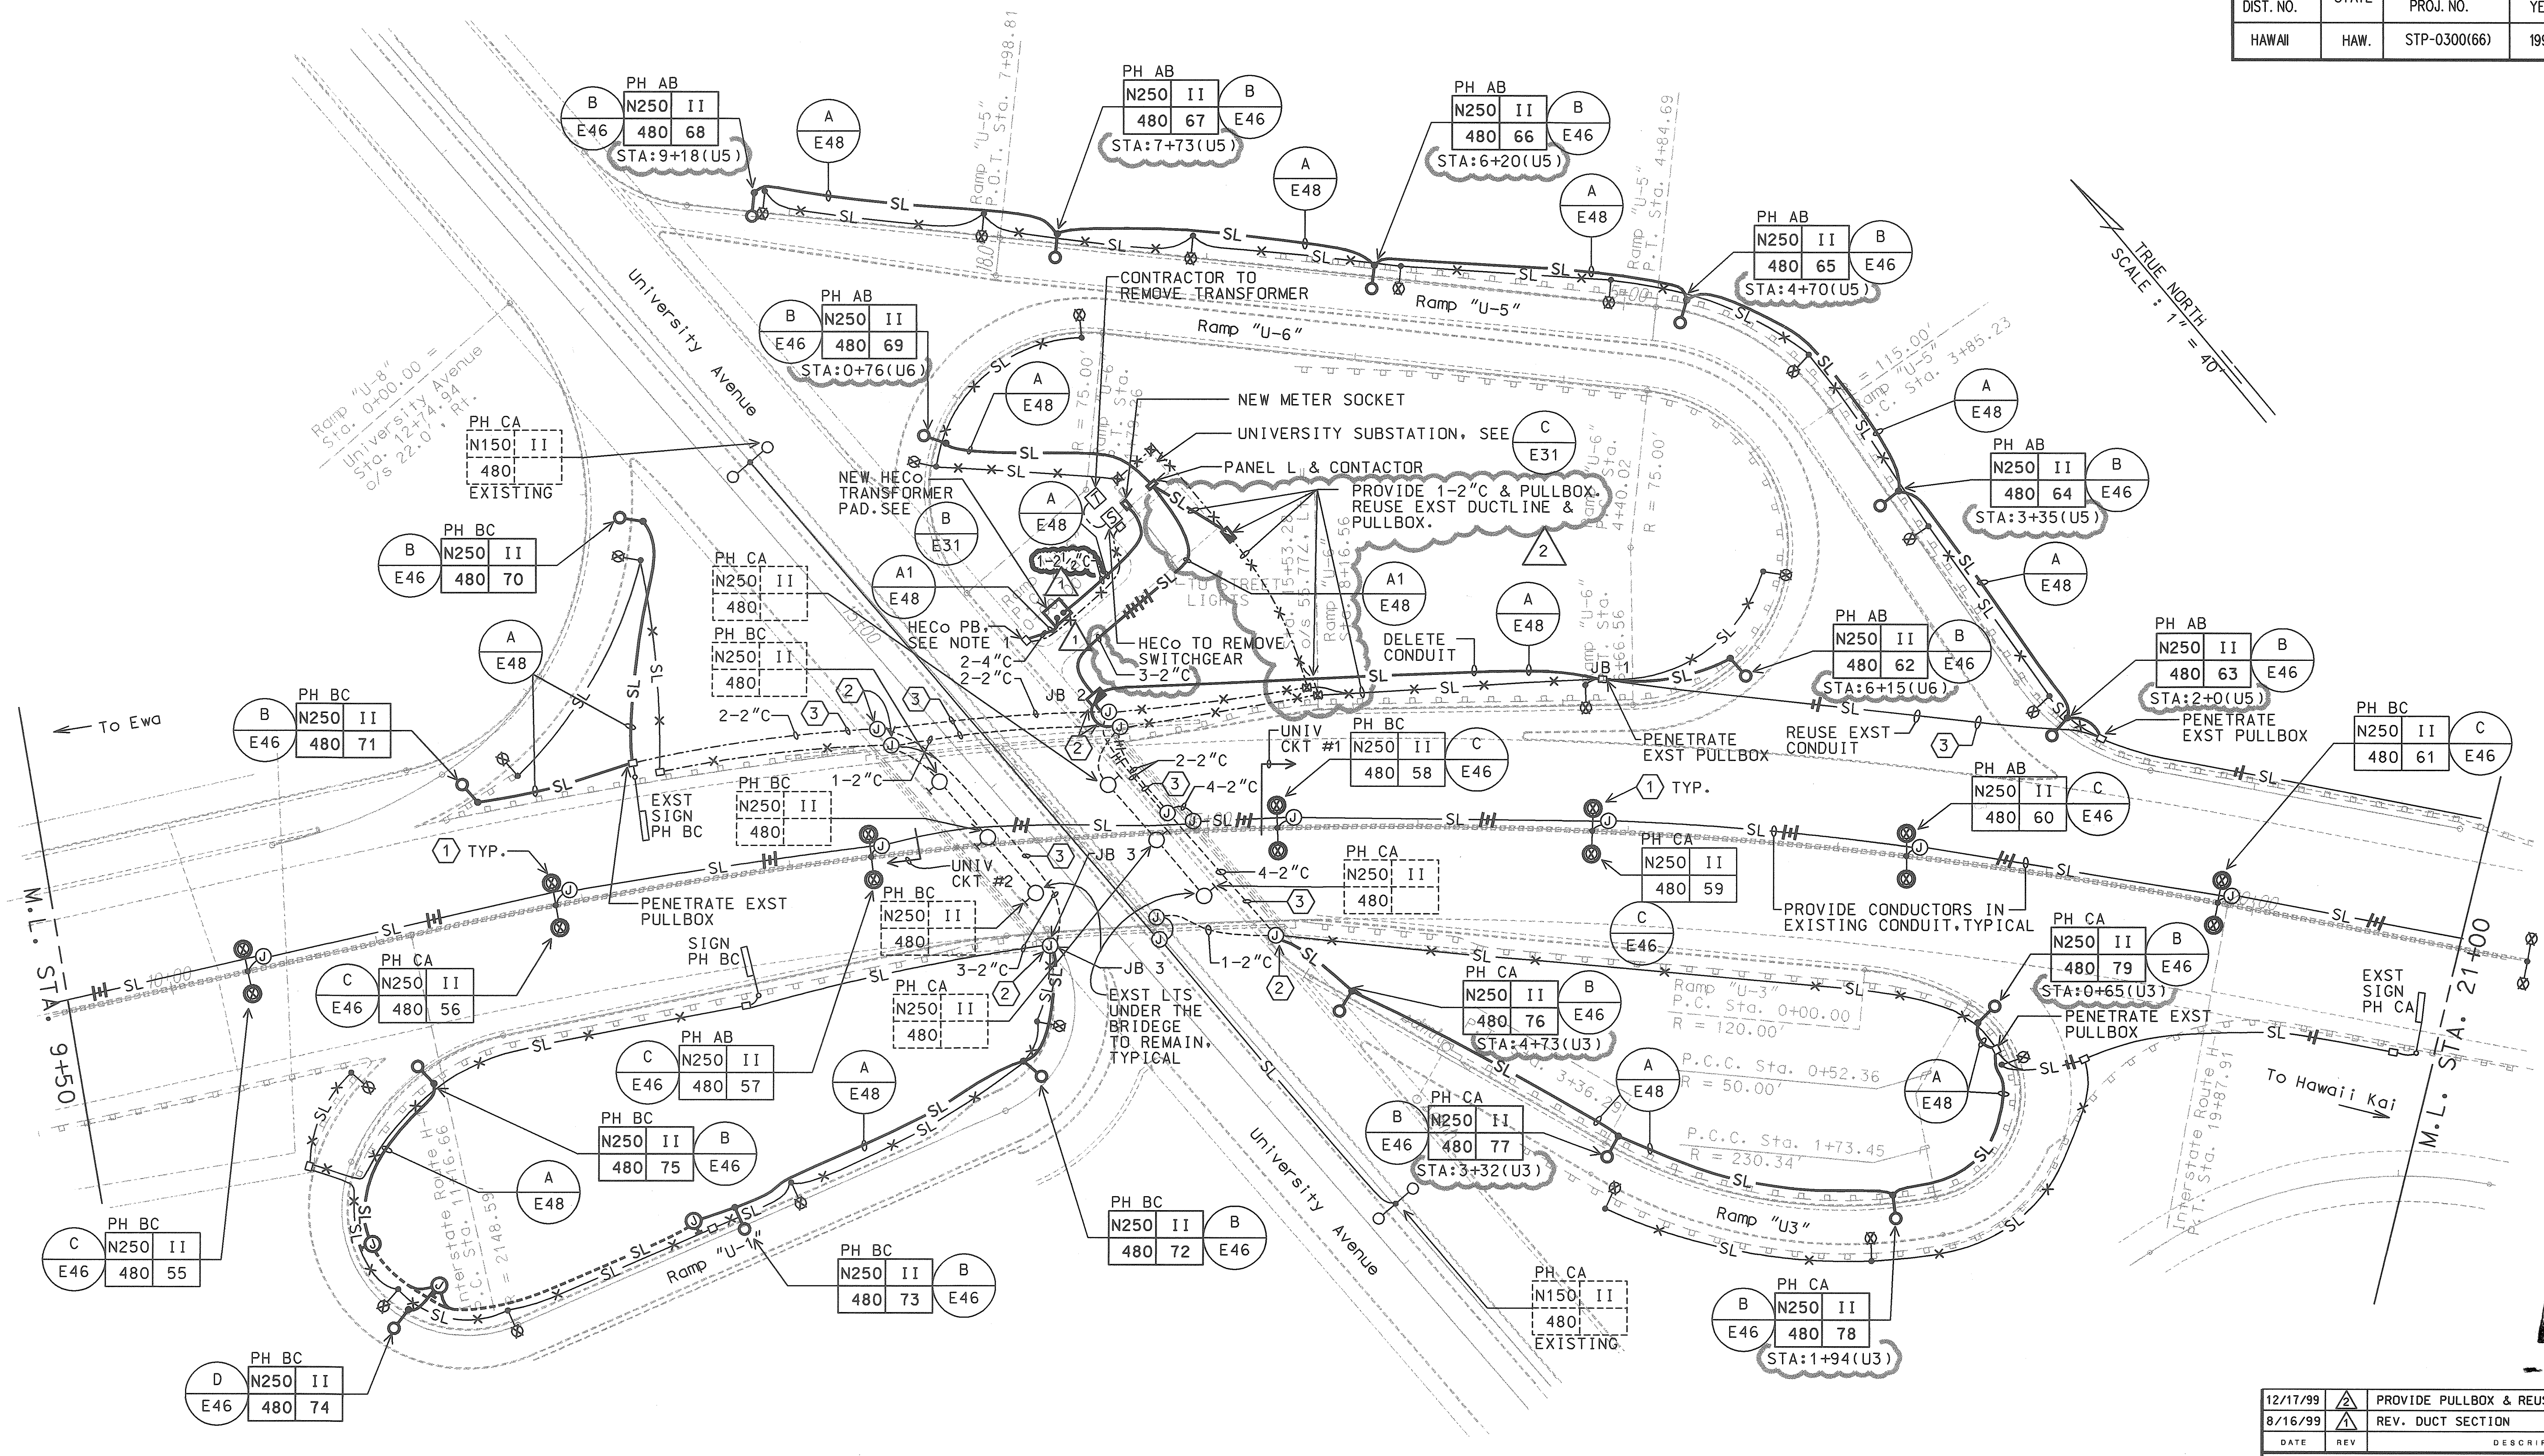

HIGHWAY LIGHTING PLAN
SCALE: 1" = 40'

- NOTES:
1. PENETRATE EXISTING HECO PULLBOX. COORDINATE WITH HECO.

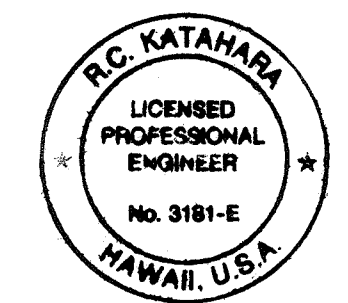


THIS WORK WAS PREPARED BY ME
OR UNDER MY SUPERVISION.
R.C. KATAHARA
ENGINEERS, LTD.


12/17/99	△	PROVIDE PULLBOX & REUSE EXST CONDUITS
8/16/99	△	REV. DUCT SECTION
DATE	REV	DESCRIPTION
STATE OF HAWAII DEPARTMENT OF TRANSPORTATION HIGHWAYS DIVISION HIGHWAY LIGHTING PLAN HIGHWAY LIGHTING SAFETY IMPROVEMENTS INTERSTATE ROUTE H-1 KEEAUMOKU STREET TO AINAKO AVE PROJECT NO. STP-0300(66) SCALE: AS NOTED DATE: JANUARY 1999 SHEET No. E35 OF 56 SHEETS		

C0-E35

FED. ROAD DIST. NO.	STATE	FED. AID PROJ. NO.	FISCAL YEAR	SHEET NO.	TOTAL SHEETS
HAWAII	HAW.	STP-0300(66)	1998		

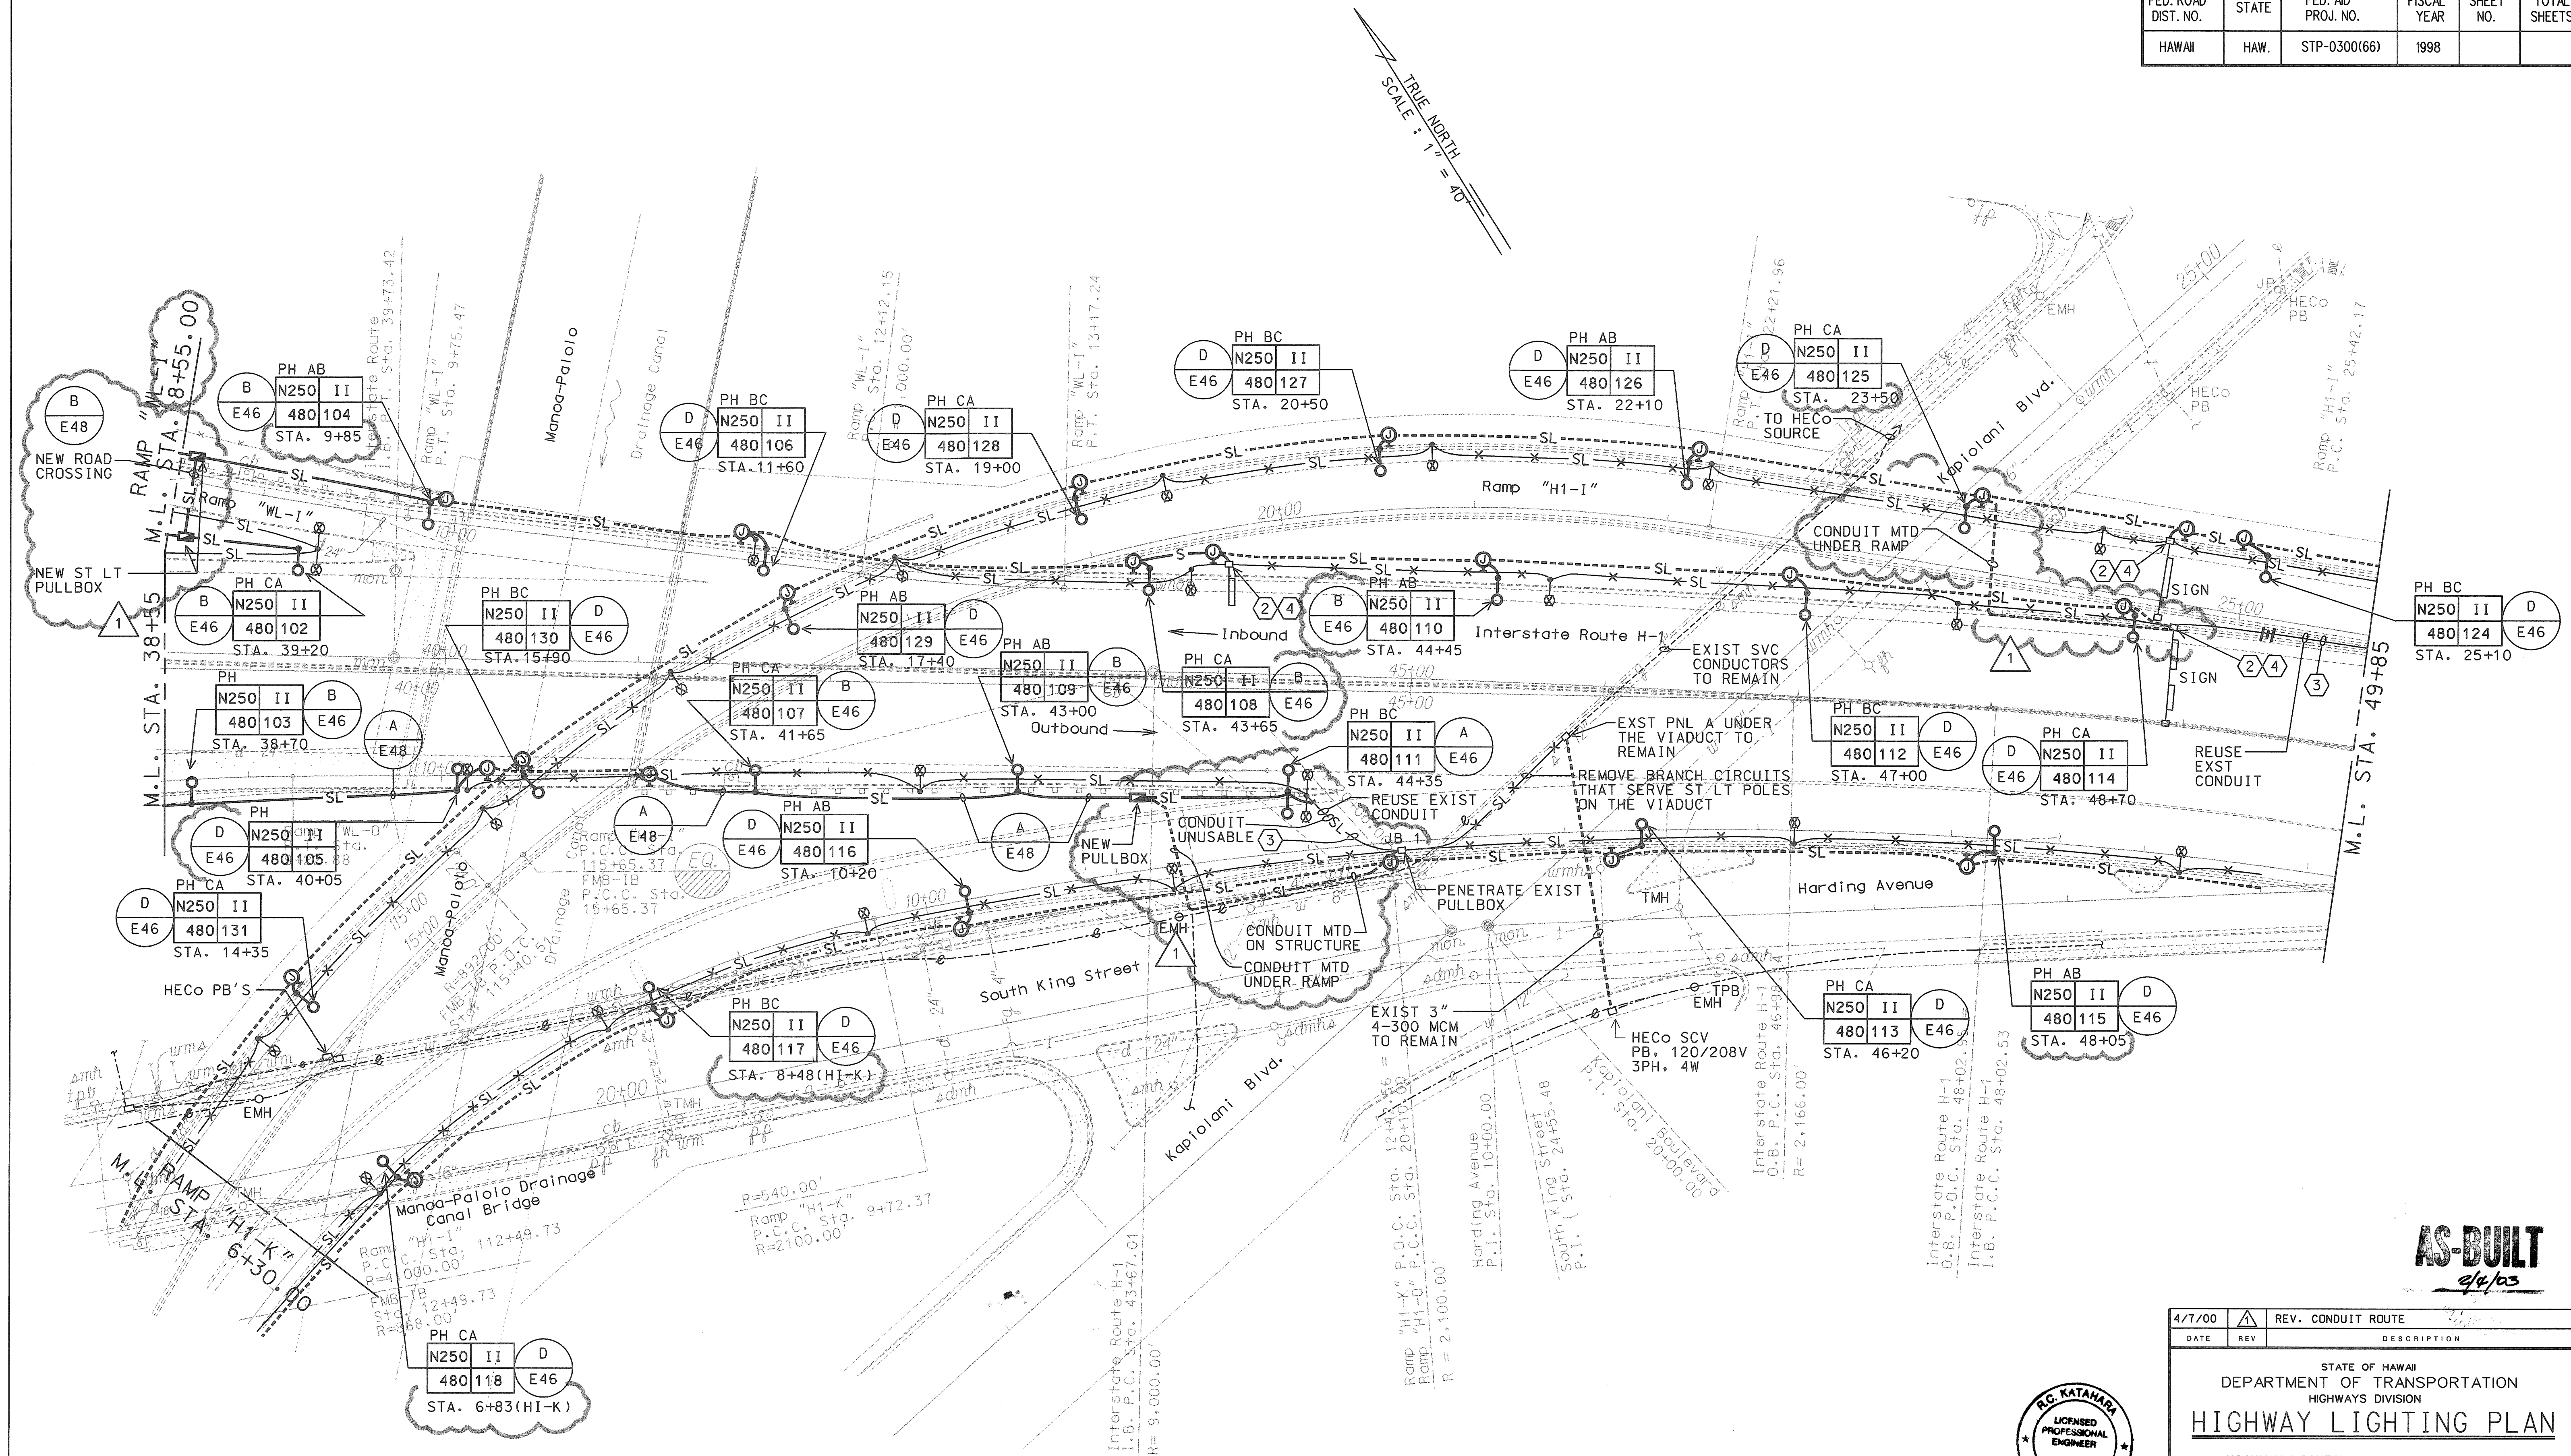

HIGHWAY LIGHTING PLAN
SCALE: 1" = 40'



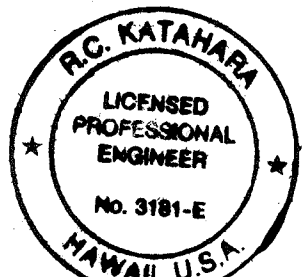


THIS WORK WAS PREPARED BY ME
OR UNDER MY SUPERVISION.
R.C. Katanaka 11/25/98
MR. ENGINEERS, LTD.


DATE	REV	DESCRIPTION
4/7/00	1	REV. CONDUIT ROUTE

STATE OF HAWAII DEPARTMENT OF TRANSPORTATION HIGHWAYS DIVISION HIGHWAY LIGHTING PLAN HIGHWAY LIGHTING SAFETY IMPROVEMENTS INTERSTATE ROUTE H-1 KEEAUMOKU STREET TO AINAKOA AVE PROJECT NO. STP-0300(66.) SCALE: AS NOTED DATE: JANUARY 1999 SHEET No. E37 OF 56 SHEETS


FED. ROAD DIST. NO.	STATE	FED. AID PROJ. NO.	FISCAL YEAR	SHEET NO.	TOTAL SHEETS
HAWAII	HAW.	STP-0300(66)	1998		

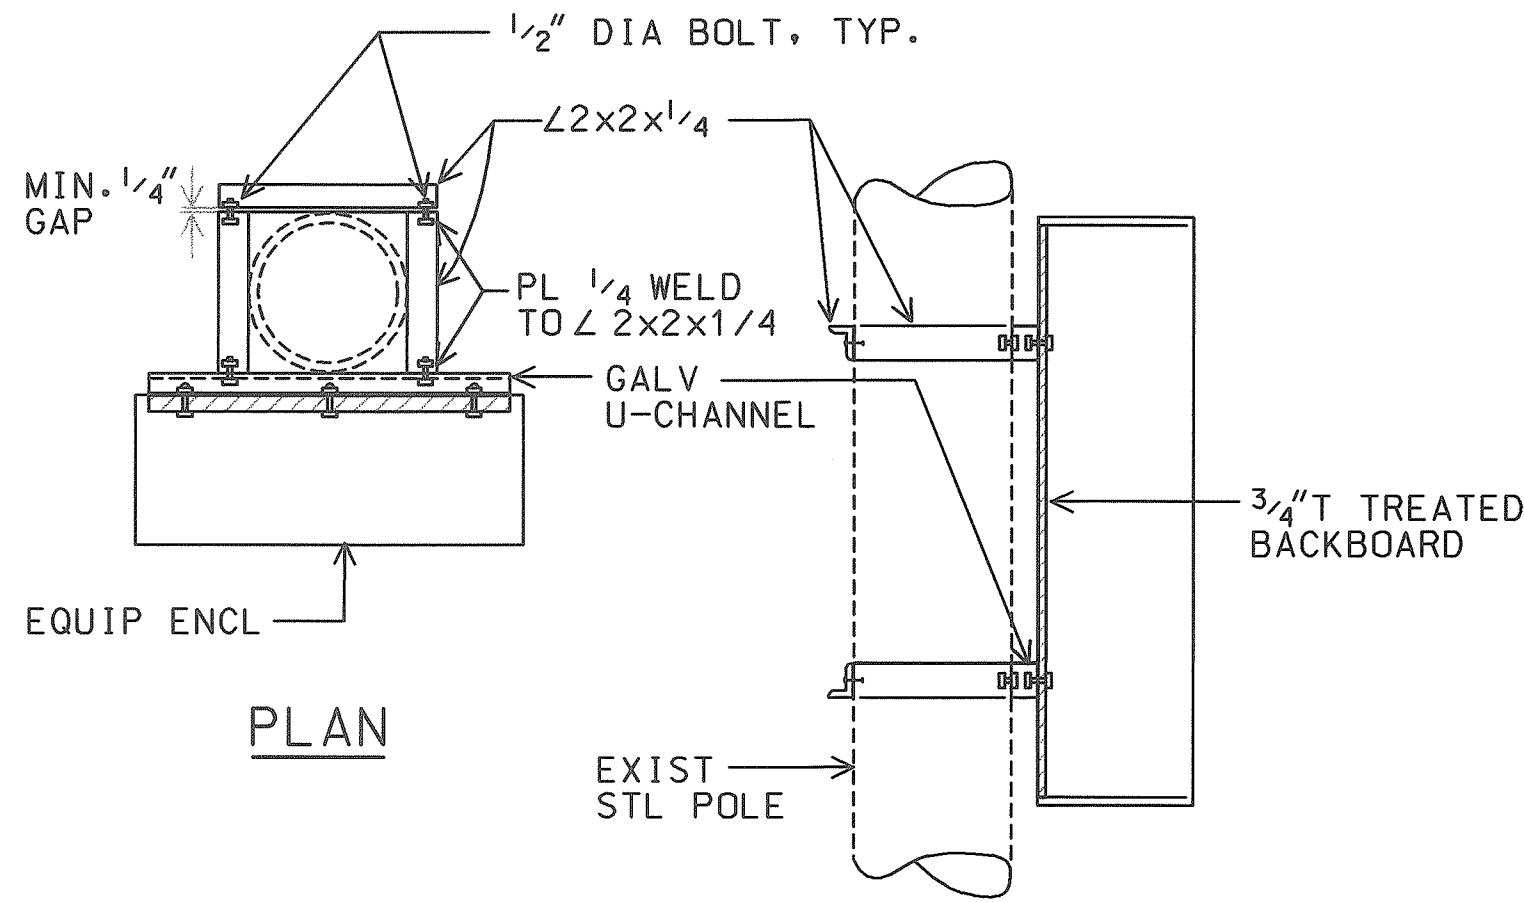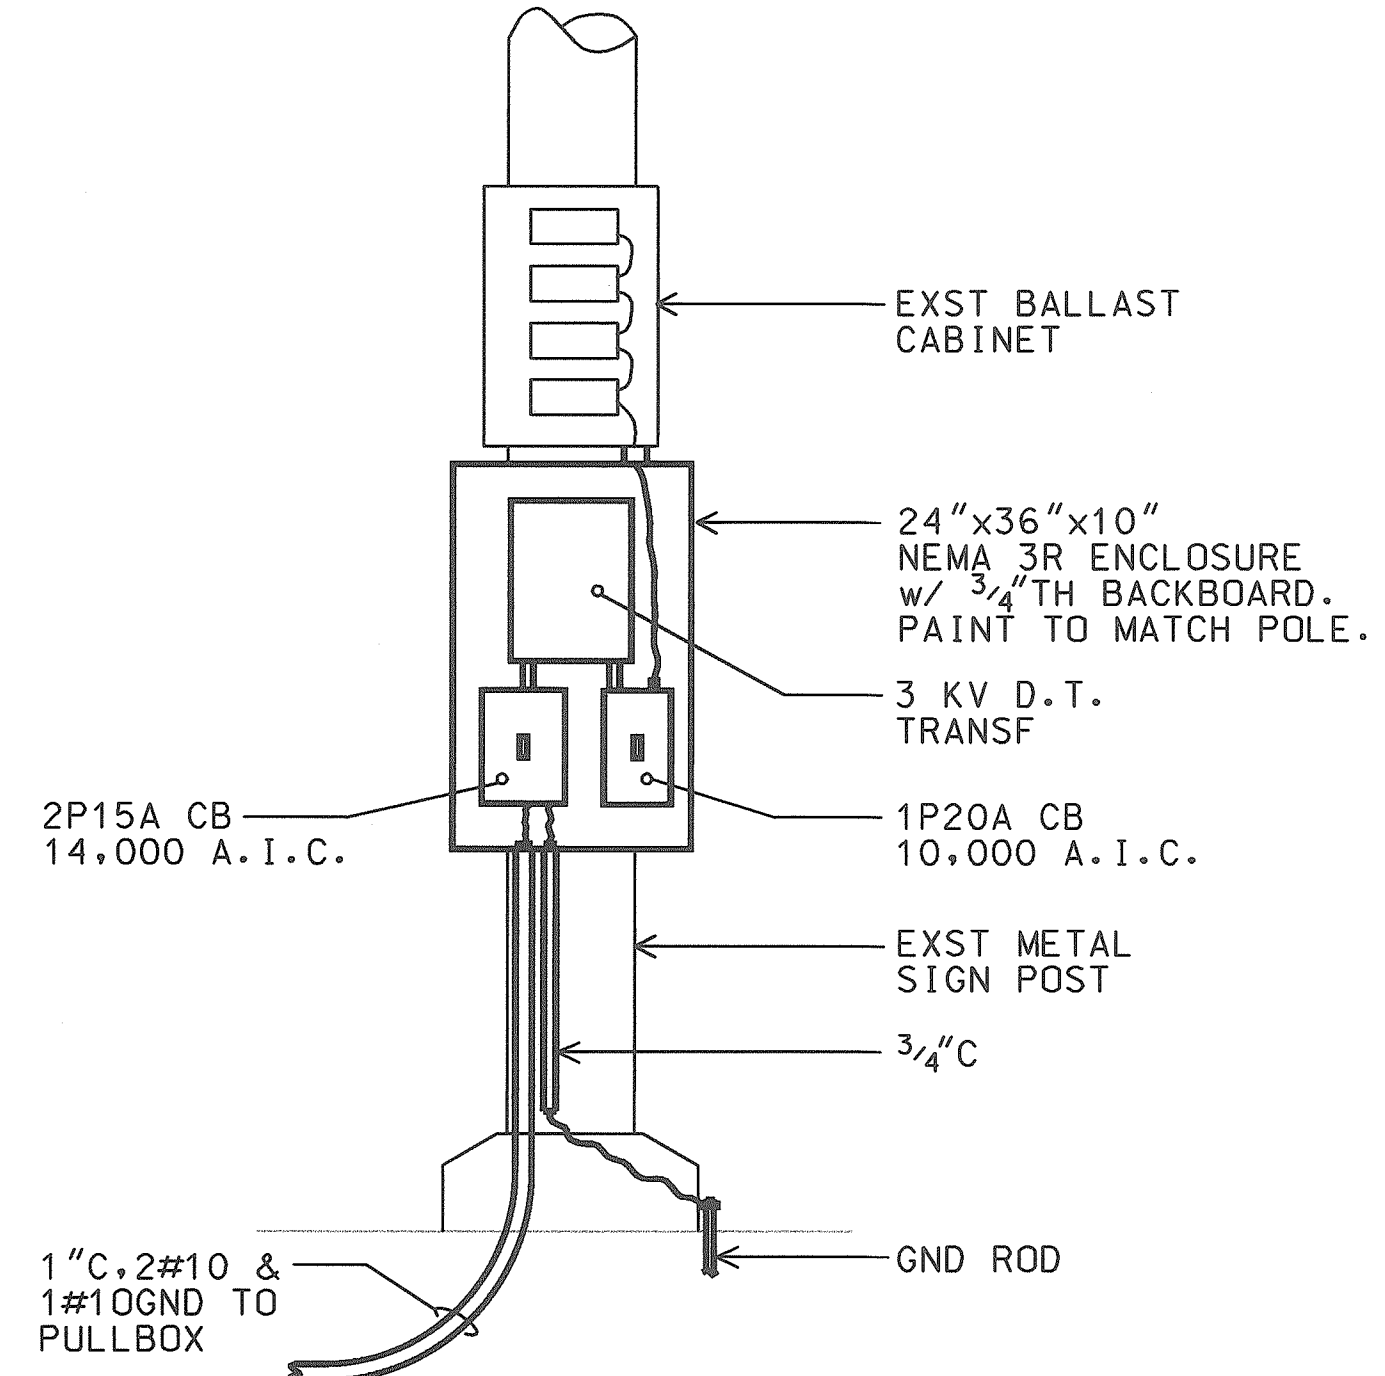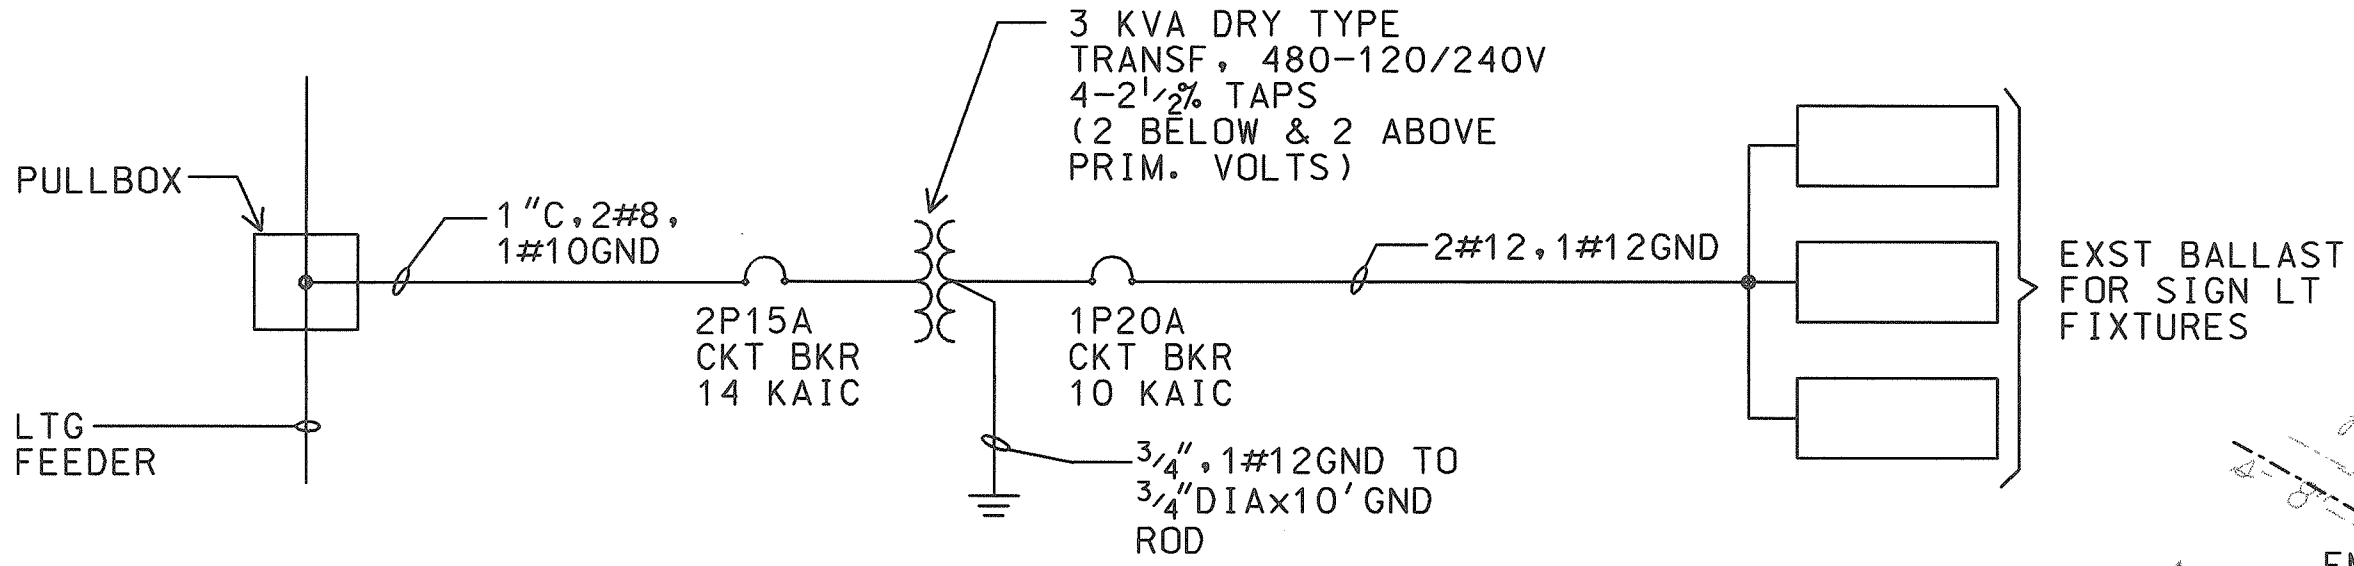

A
E38

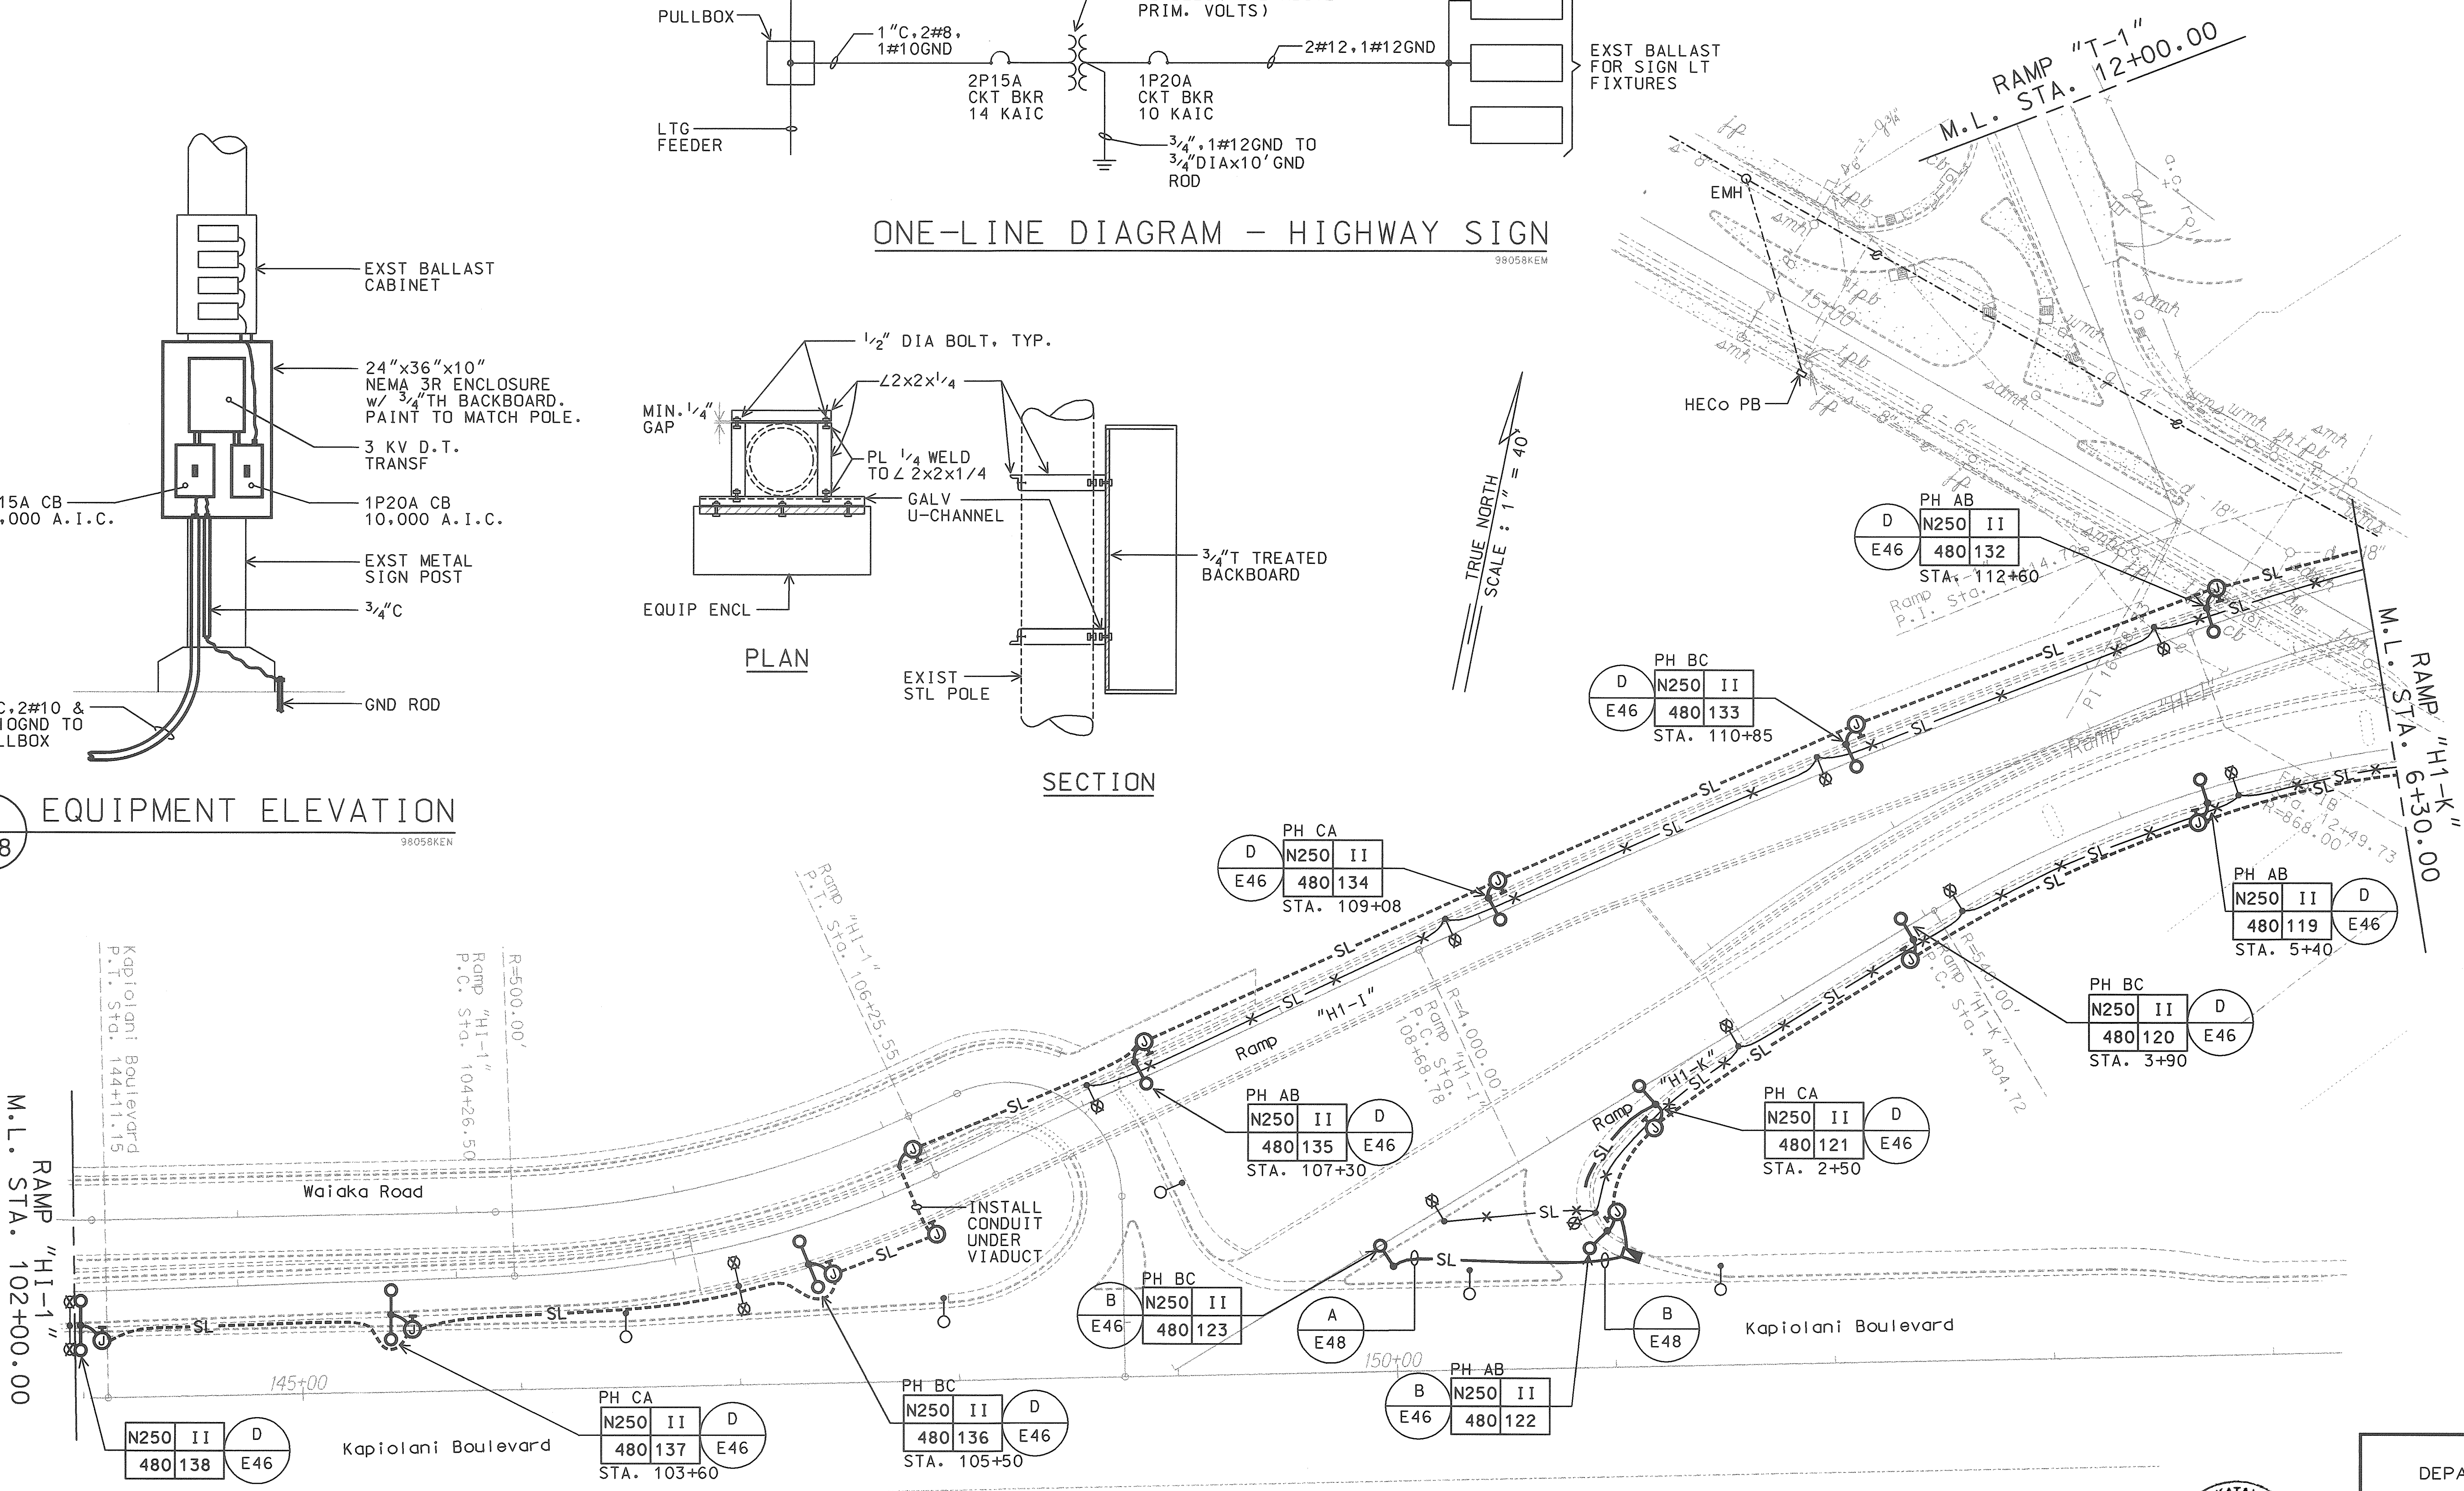

HIGHWAY LIGHTING PLAN

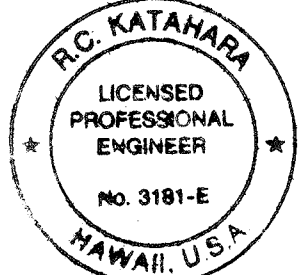

THIS WORK WAS PREPARED BY ME OR UNDER MY SUPERVISION.
R.C. KATAHARA 1/25/98
MK ENGINEERS, LTD.

STATE OF HAWAII
DEPARTMENT OF TRANSPORTATION
HIGHWAYS DIVISION


HIGHWAY LIGHTING PLAN

HIGHWAY LIGHTING SAFETY IMPROVEMENTS
INTERSTATE ROUTE H-1
KEEAUMOKU STREET TO AINAKOA AVE

PROJECT NO. STP-0300(66)
SCALE: AS NOTED DATE: JANUARY 1999
SHEET No. E38 OF 56 SHEETS


AS-BUILT
2/4/03

FED. ROAD DIST. NO.	STATE	FED. AID PROJ. NO.	FISCAL YEAR	SHEET NO.	TOTAL SHEETS
HAWAII	HAW.	STP-0300(66)	1998		

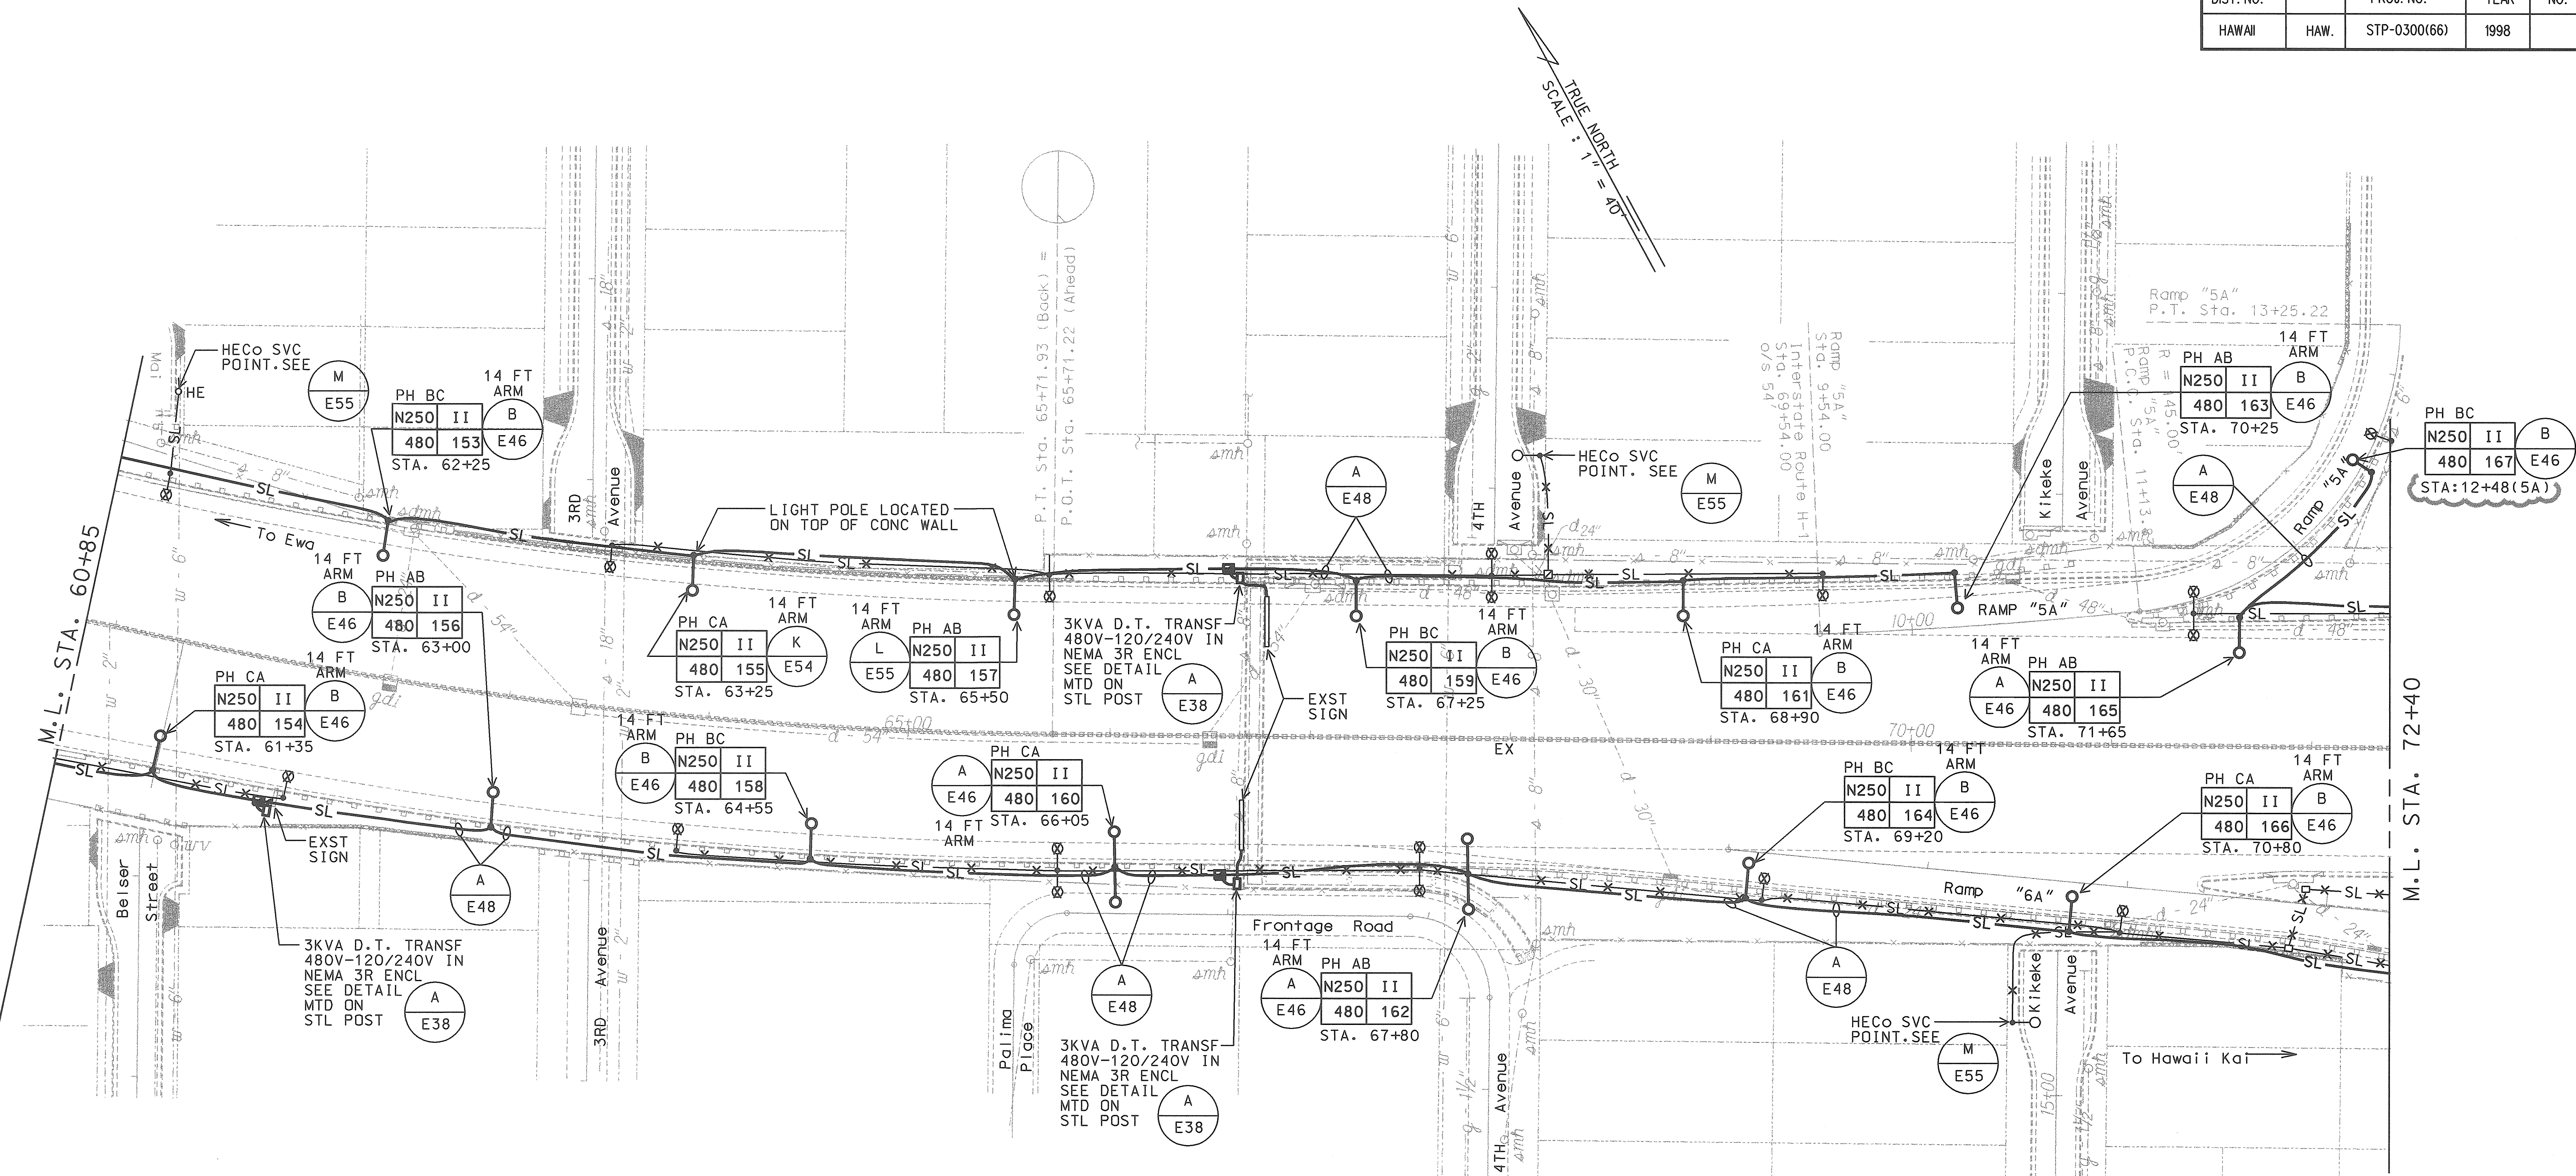

HIGHWAY LIGHTING PLAN
SCALE: 1" = 40'

AS-BUILT
2/4/00

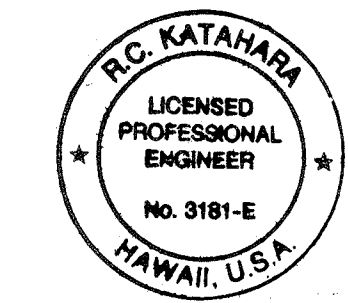

THIS WORK WAS PREPARED BY ME
OR UNDER MY SUPERVISION.
R.C. KATAHARA 1/25/98
MK ENGINEERS, LTD.


STATE OF HAWAII
DEPARTMENT OF TRANSPORTATION
HIGHWAYS DIVISION

HIGHWAY LIGHTING PLAN

HIGHWAY LIGHTING SAFETY IMPROVEMENTS
INTERSTATE ROUTE H-1
KEEAUMOKU STREET TO AINAKOA AVE

PROJECT NO. STP-0300(66)
SCALE: AS NOTED DATE: JANUARY 1999
SHEET No. 40 OF 56 SHEETS

TRUE NORTH
SCALE : 1" = 40'

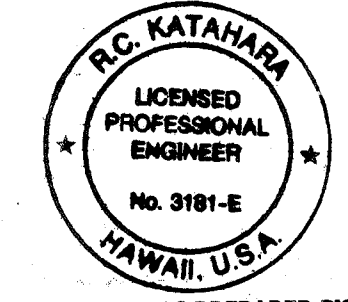

THIS WORK WAS PREPARED BY ME
OR UNDER MY SUPERVISION.
PC Katahan 11/25/98
MK ENGINEERS, LTD.

AS-BUILT
2/4/03
DATE

STATE OF HAWAII
DEPARTMENT OF TRANSPORTATION
HIGHWAYS DIVISION

HIGHWAY LIGHTING PLAN



HIGHWAY LIGHTING SAFETY IMPROVEMENTS
INTERSTATE ROUTE H-1
KEEAUMOKU STREET TO AINAKOA AVE

PROJECT NO. STP-0300(66)

SCALE: AS NOTED DATE: JANUARY 1999

SHEET No. E41 OF 56 SHEETS

FED. ROAD DIST. NO.	STATE	FED. AID PROJ. NO.	FISCAL YEAR	SHEET NO.	TOTAL SHEETS
HAWAII	HAW.	STP-0300(66)	1998		

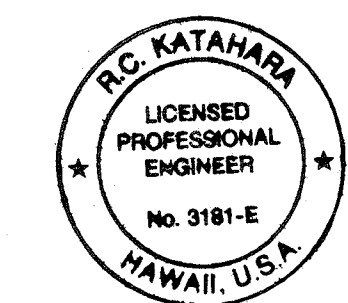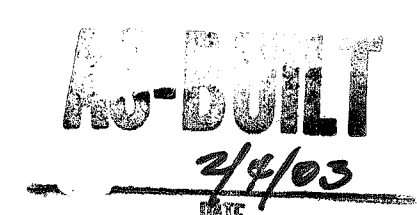

THIS WORK WAS PREPARED BY ME
OR UNDER MY SUPERVISION.
M. K. Kataria 11/25/98
MK ENGINEERS, LTD.


STATE OF HAWAII
DEPARTMENT OF TRANSPORTATION
HIGHWAYS DIVISION
HIGHWAY LIGHTING PLAN

HIGHWAY LIGHTING SAFETY IMPROVEMENTS
INTERSTATE ROUTE H-1
KEEAUMOKU STREET TO AINAKOA AVE

PROJECT NO. STP-0300(66)
SCALE: AS NOTED DATE: JANUARY 1999
SHEET No. E42 OF 56 SHEETS



FED. ROAD DIST. NO.	STATE	FED. AID PROJ. NO.	FISCAL YEAR	SHEET NO.	TOTAL SHEETS
HAWAII	HAW.	STP-0300(66)	1998		

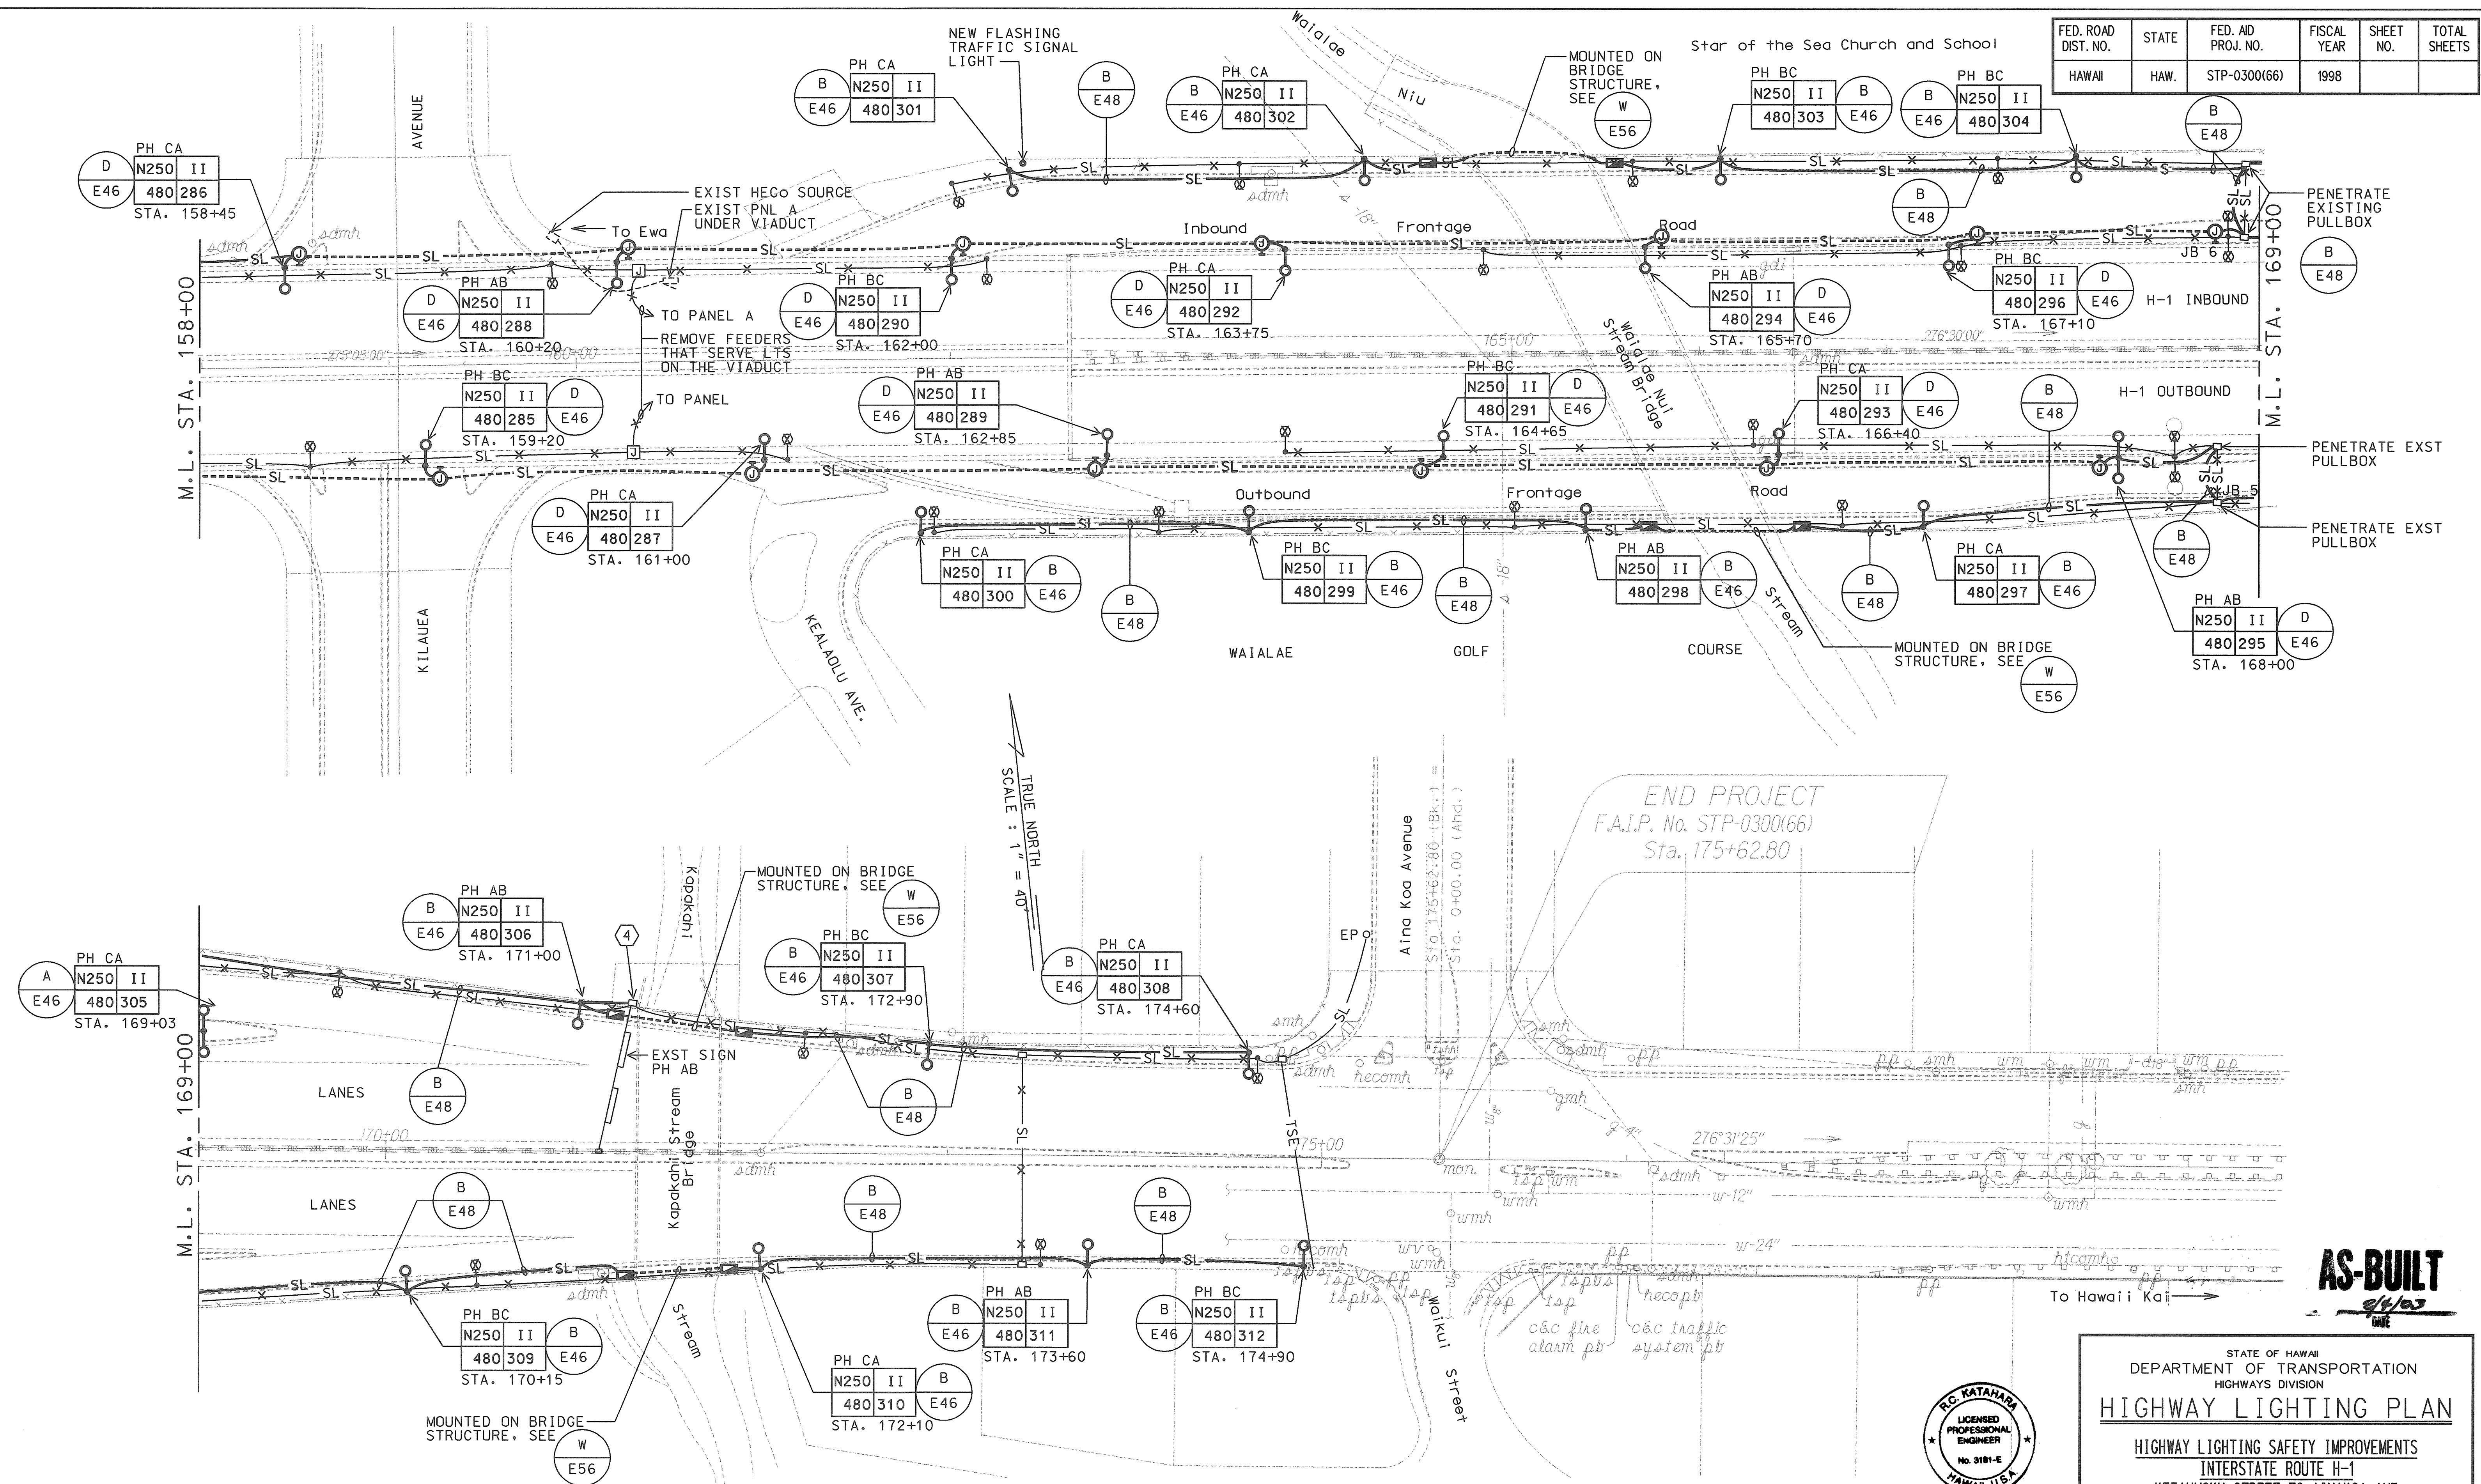

HIGHWAY LIGHTING PLAN
SCALE: 1" = 40' 98058-KN

THIS WORK WAS PREPARED BY ME
OR UNDER MY SUPERVISION.
McKathum 1/25/98
MK ENGINEERS, LTD.

STATE OF HAWAII
DEPARTMENT OF TRANSPORTATION
HIGHWAYS DIVISION

HIGHWAY LIGHTING PLAN





HIGHWAY LIGHTING SAFETY IMPROVEMENTS
INTERSTATE ROUTE H-1
KEEAUMOKU STREET TO AINAKOA AVE

PROJECT NO. STP-0300(66)

SCALE: AS NOTED DATE: JANUARY 1999

SHEET No. E45 OF 56 SHEETS

14 FT TRUSS ARM
w/ 32" RISE FOR
LT POLE 145, 147,
148, 149, 150, 151,
152, 153, 154, 156,
158, 159, 161, 163,
164, 165, 166, 171,
172, 173, 174 & 176

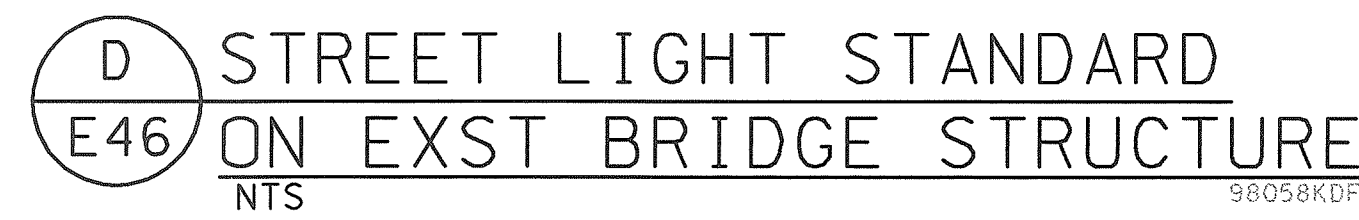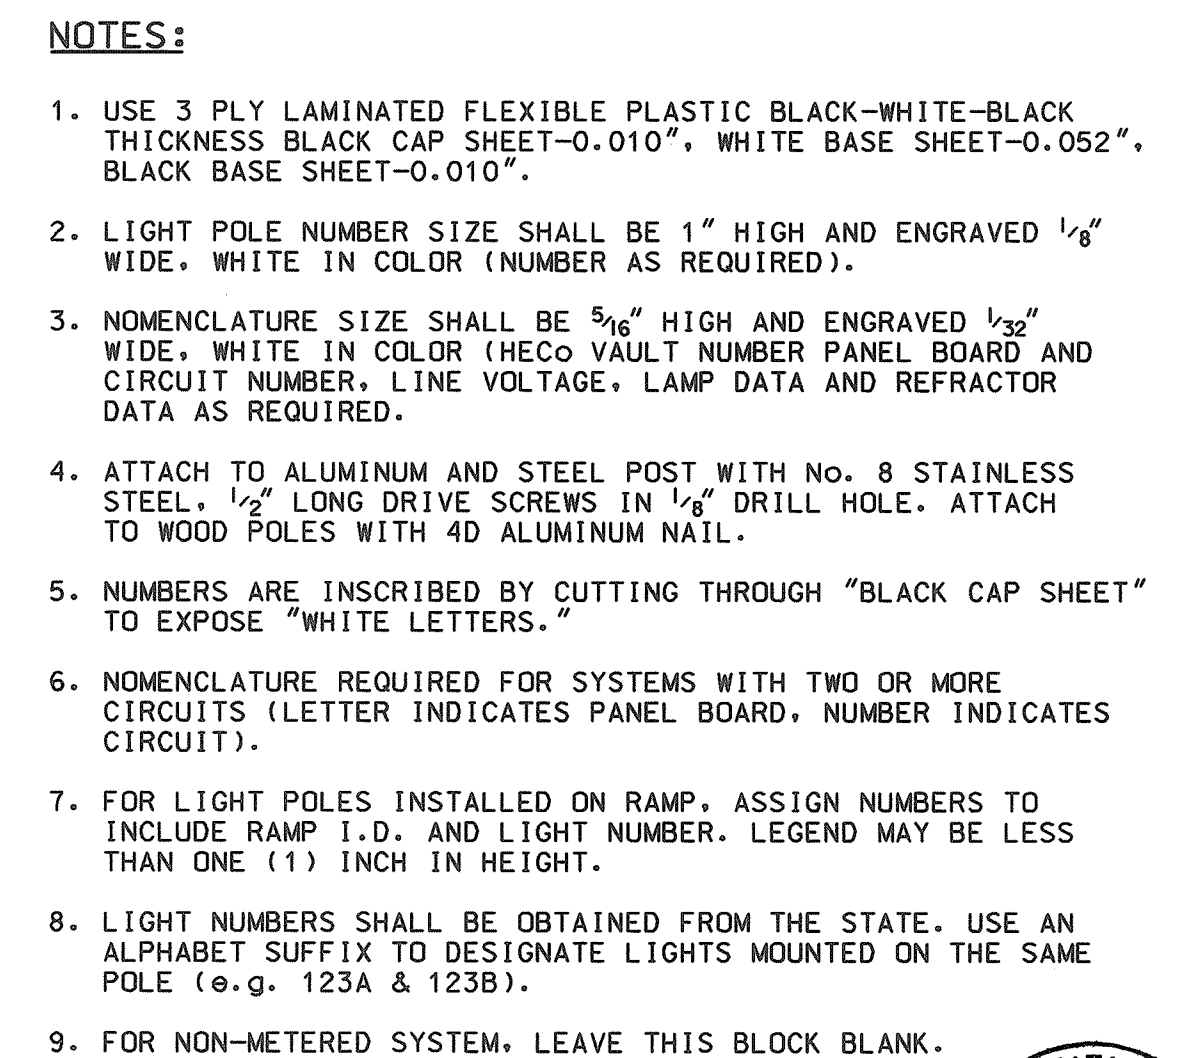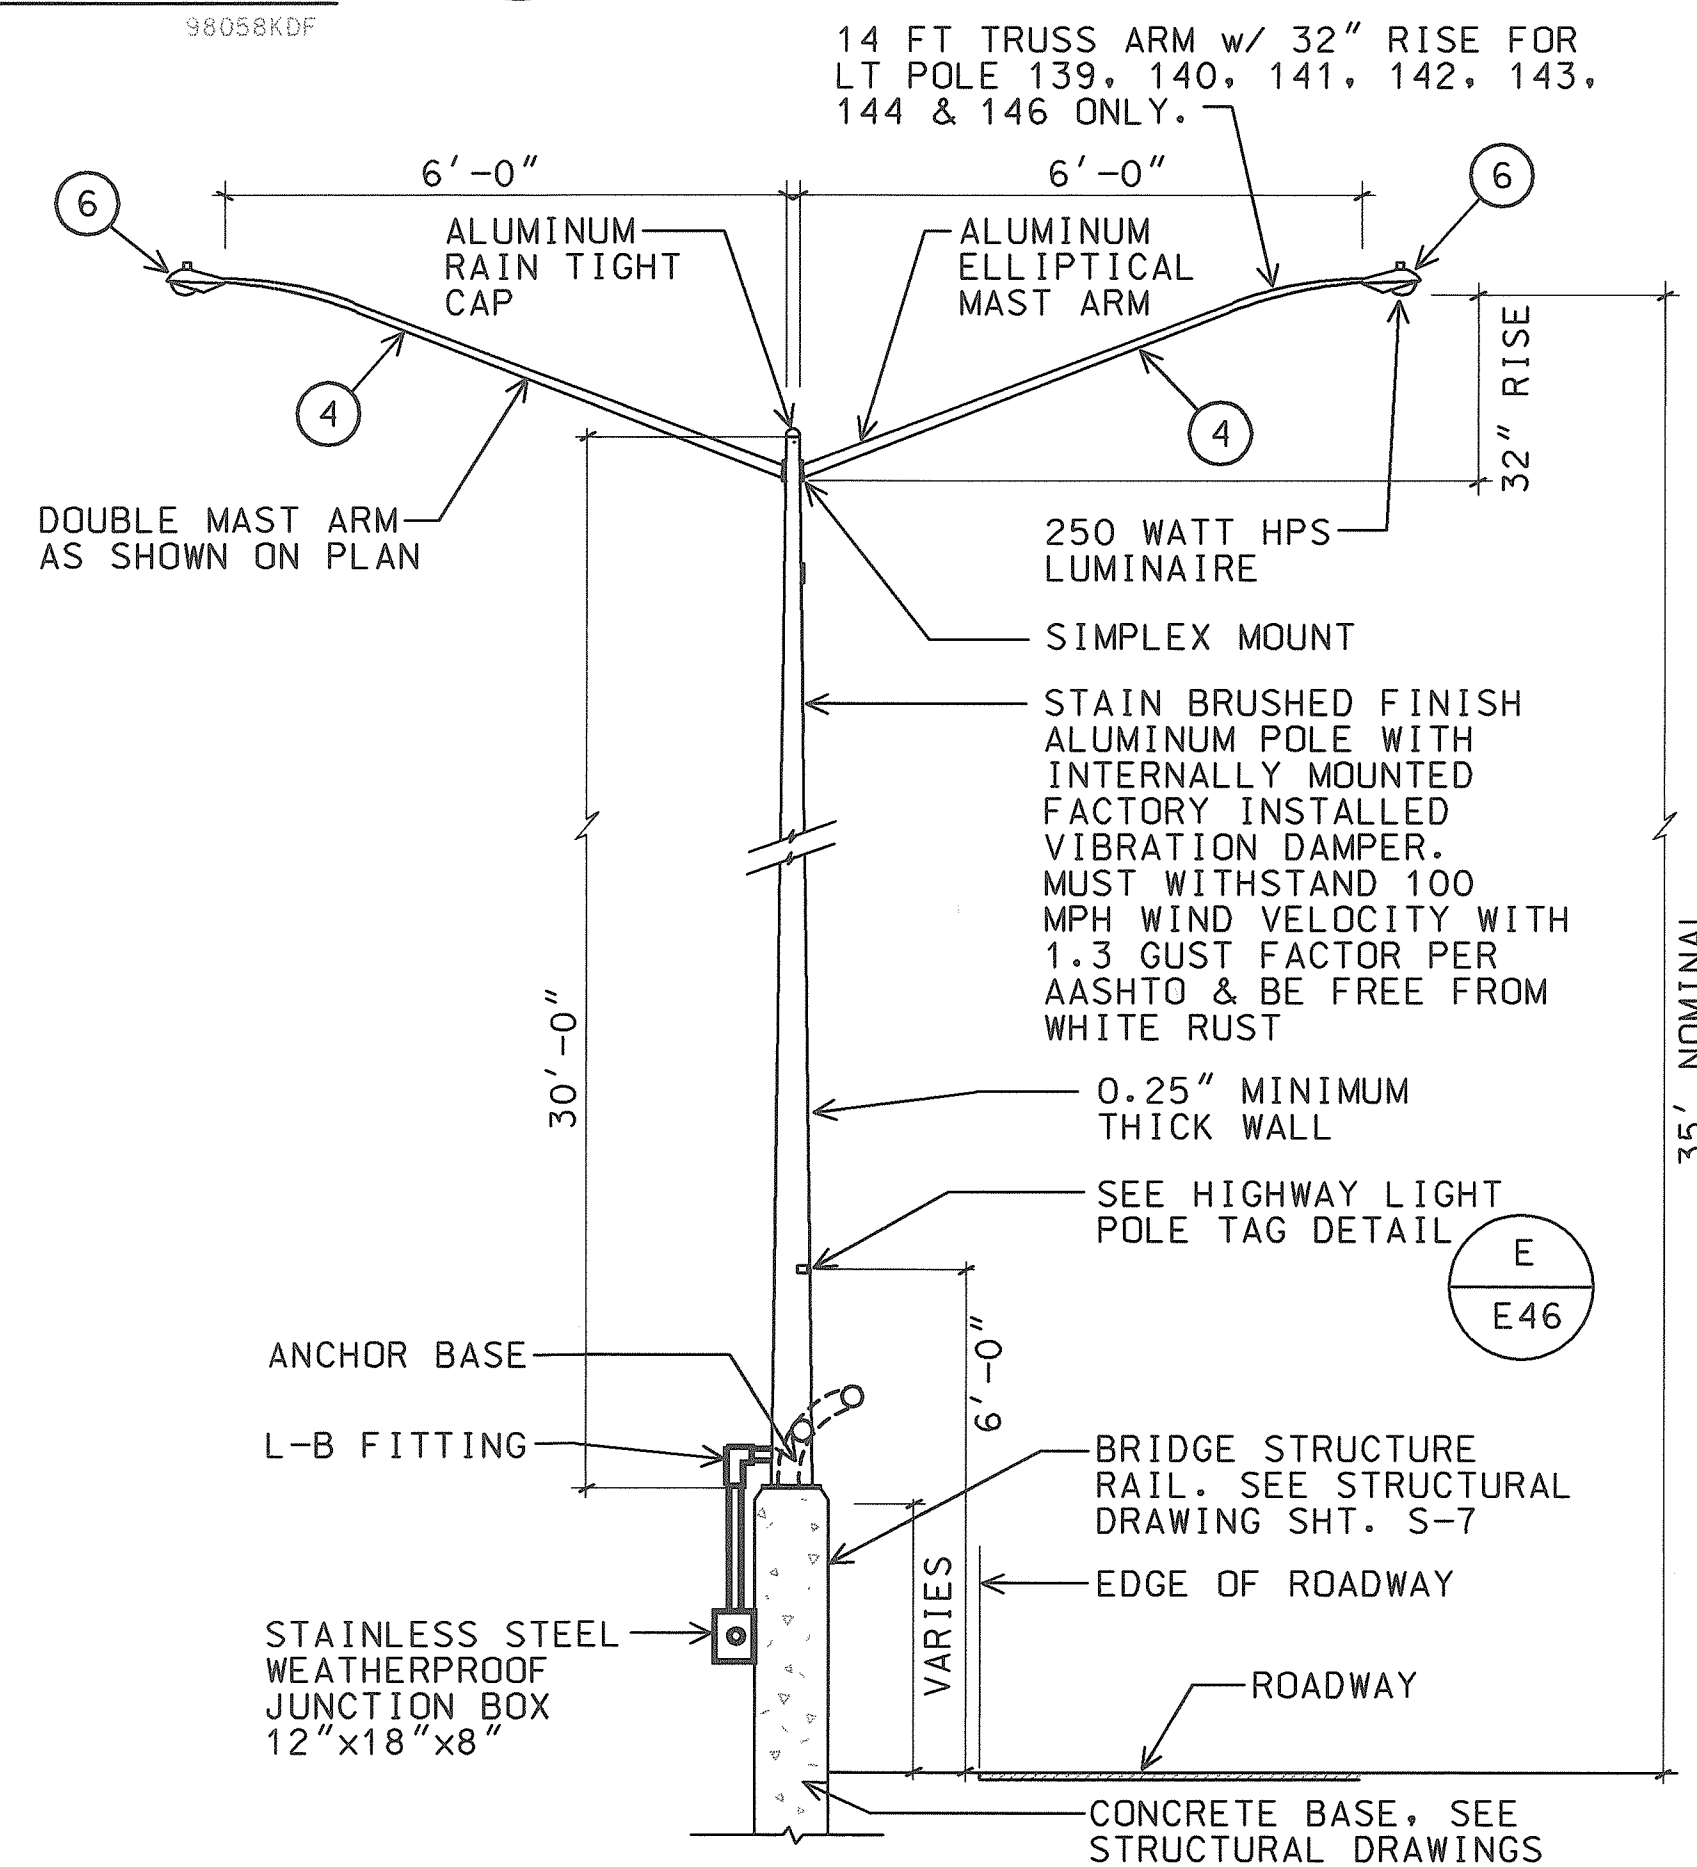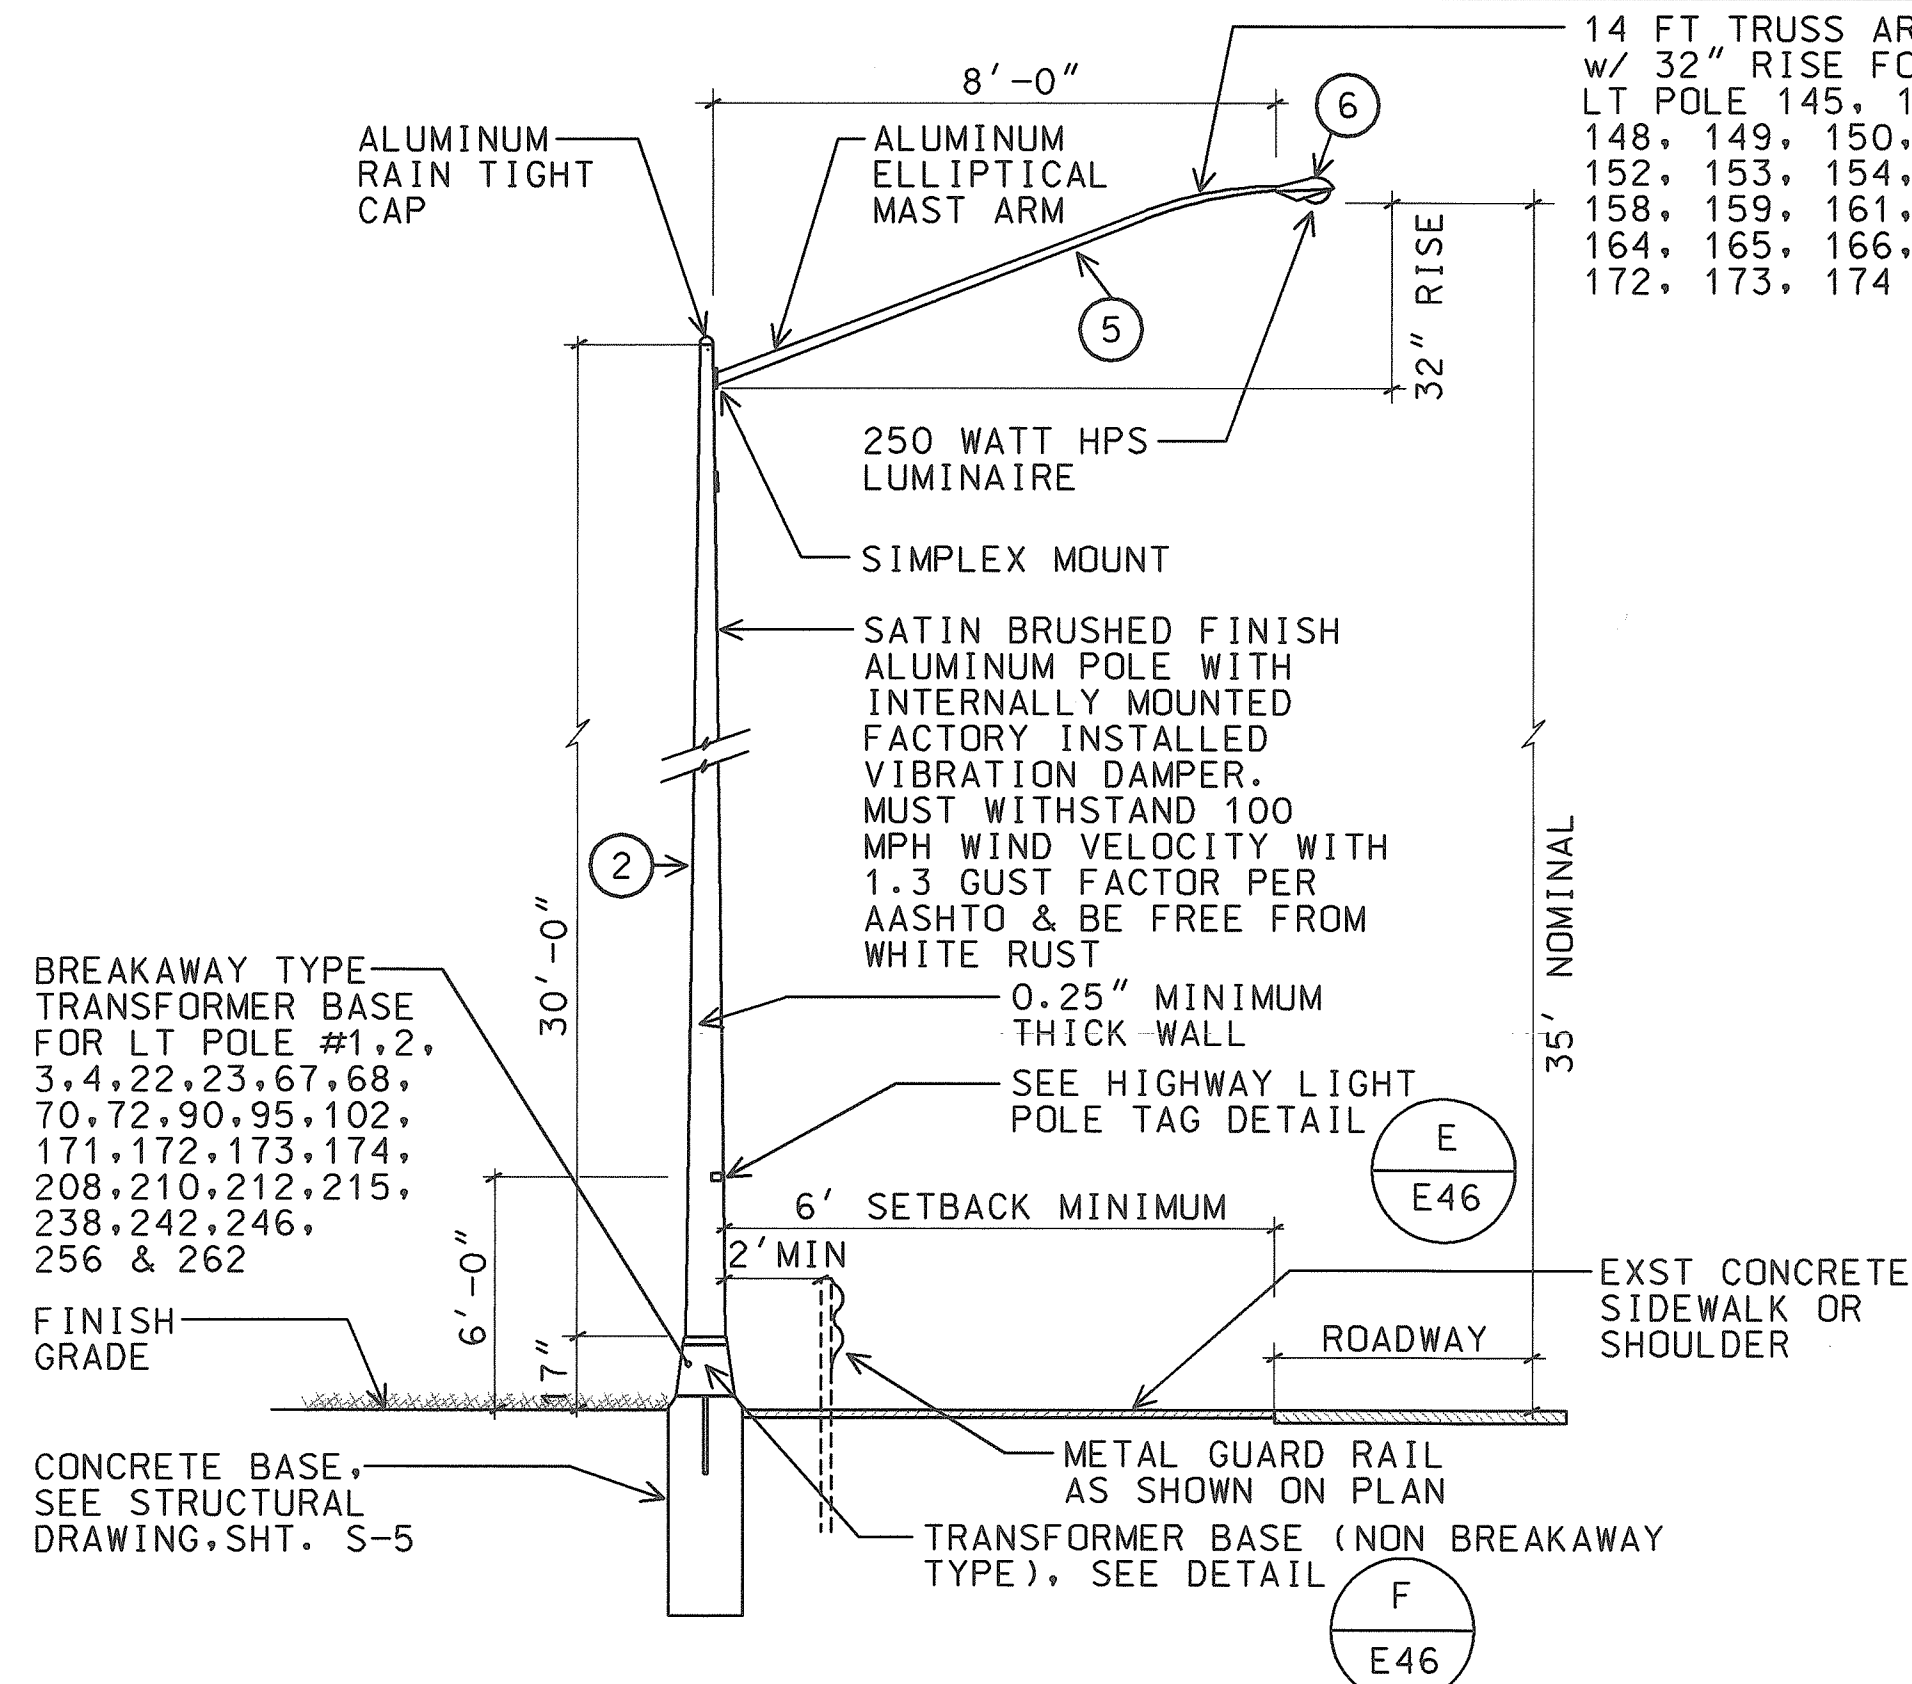

UNMETERED SYSTEM, LEAVE THIS BLOCK BLANK.

IL
6KDF


AS-BUILT
2/4/63
DATE

R.C. KATAHARA
LICENSED
PROFESSIONAL
ENGINEER
No. 3181-E
HAWAII, U.S.A.

**THIS WORK WAS PREPARED BY MR
OR UNDER MY SUPERVISION,**
Per Katakara 4/25/68
NK ENGINEERS, LTD.





STATE OF HAWAII	
DEPARTMENT OF TRANSPORTATION	
HIGHWAYS DIVISION	
<u>STREET LIGHT DETAILS</u>	
<u>HIGHWAY LIGHTING SAFETY IMPROVEMENTS</u>	
<u>INTERSTATE ROUTE H-1</u>	
<u>KEEAUMOKU STREET TO AINAKOA AVE</u>	
<u>PROJECT NO. STP-0300(66)</u>	
SCALE: AS NOTED	DATE: JANUARY 1999
SHEET No. <u>E46</u> OF <u>56</u> SHEETS	

FED. ROAD DIST. NO.	STATE	FED. AID PROJ. NO.	FISCAL YEAR	SHEET NO.	TOTAL SHEETS
HAWAII	HAW.	STP-0300(66)	1998		

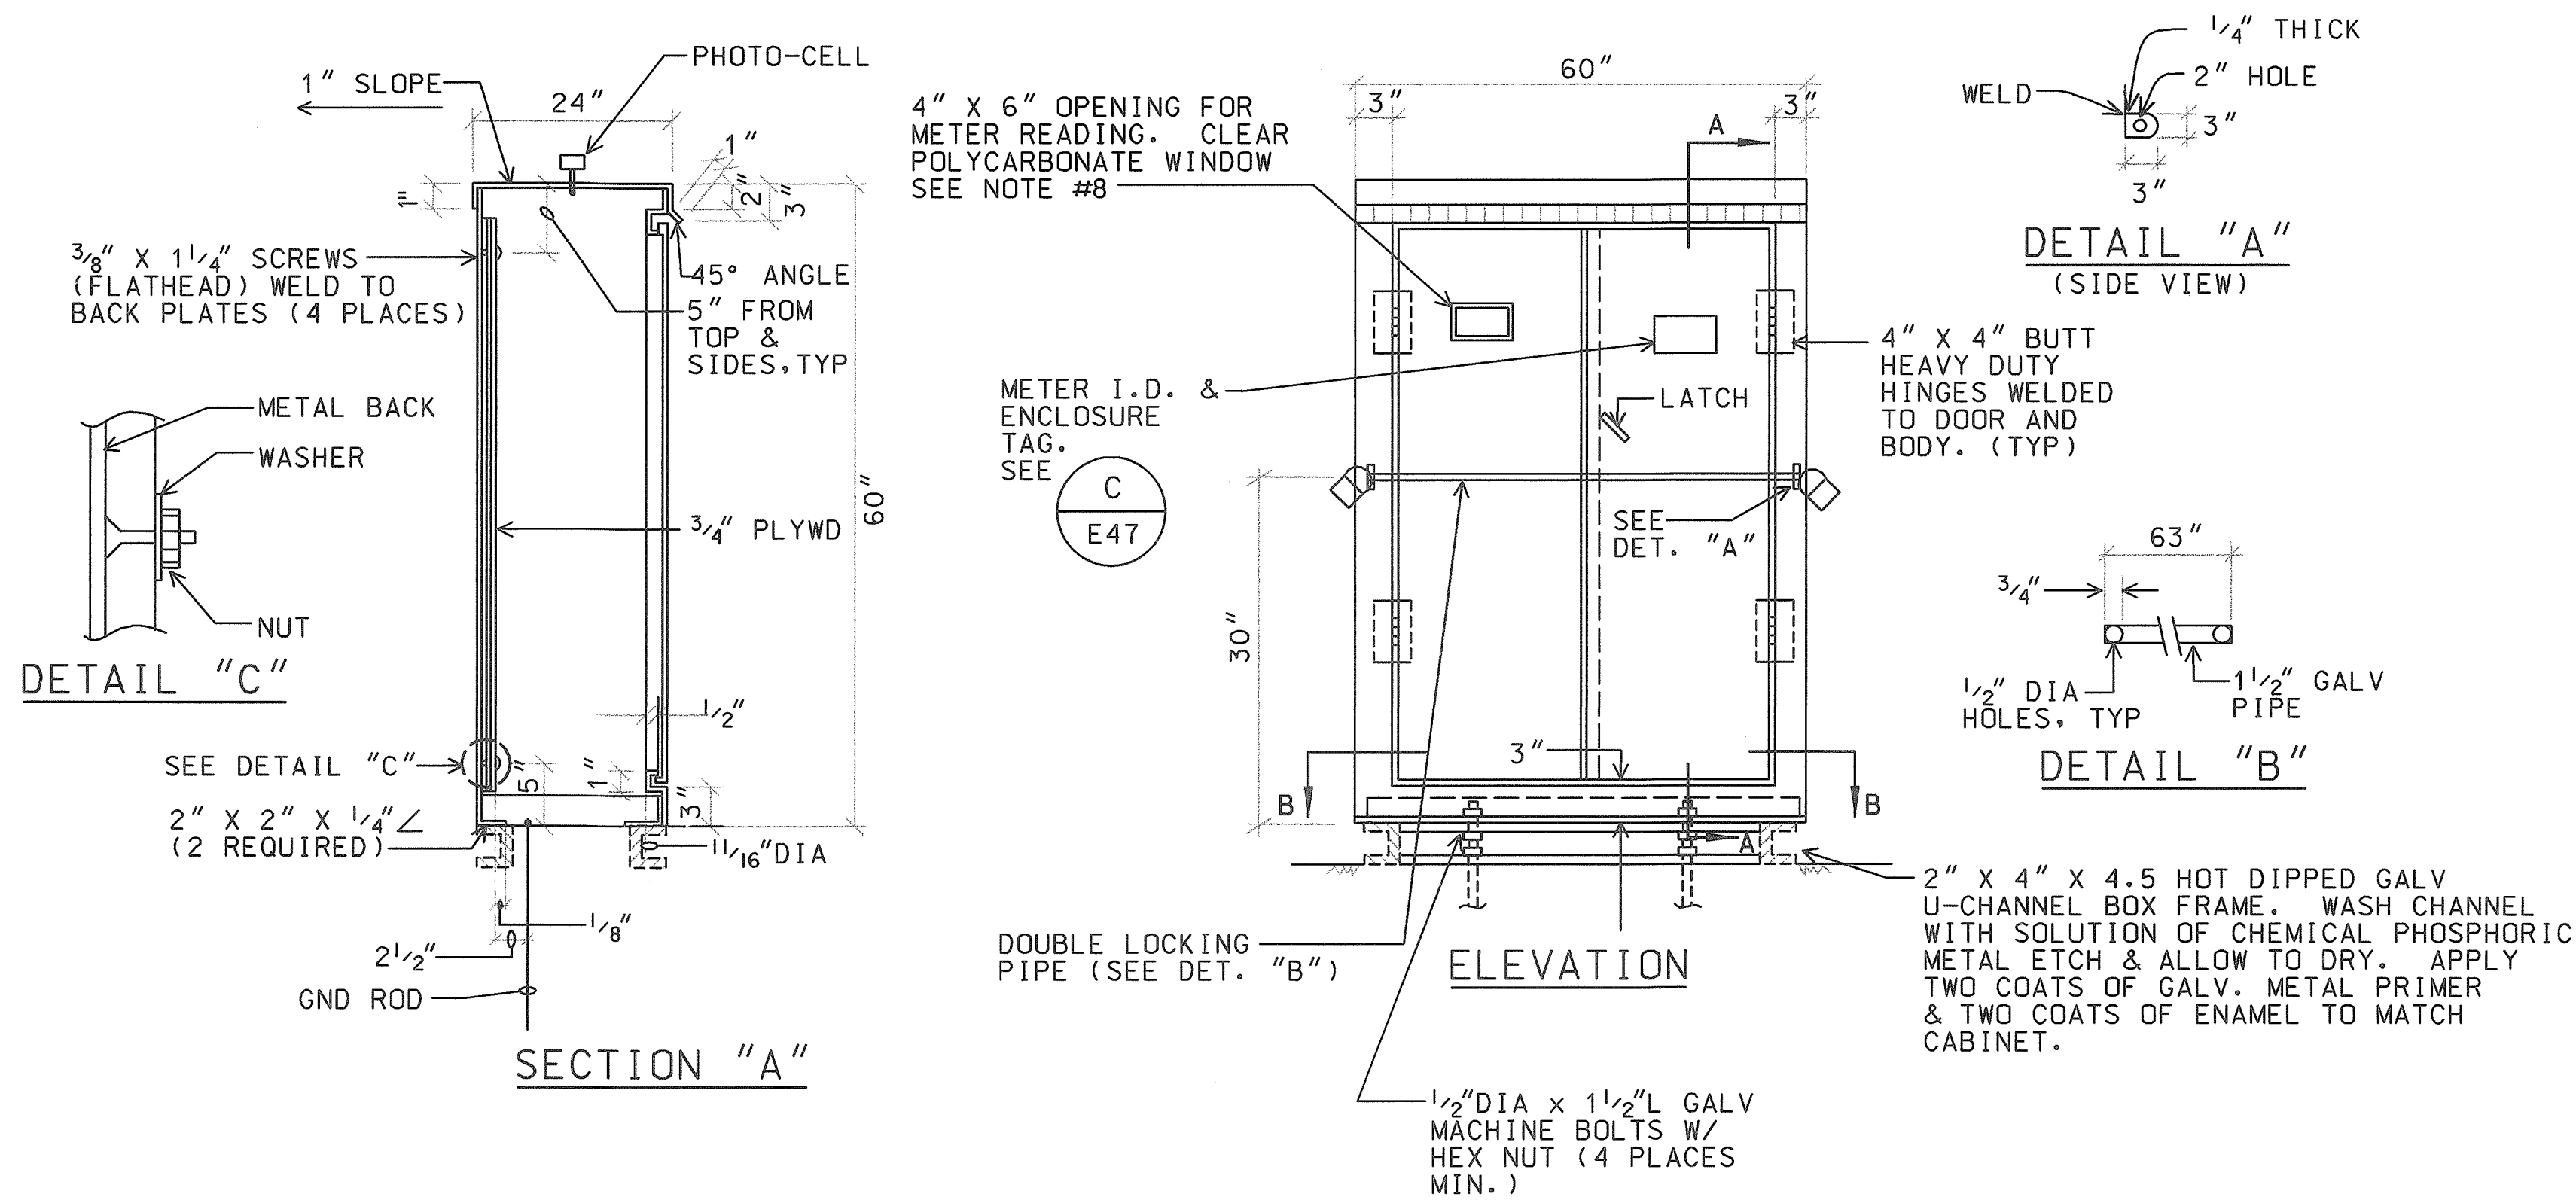


NOTES:

1. CABINET TO BE PRIMED WITH ONE COAT SHOP PRIMER.
2. PLYWOOD TO BE 3/4" THICK (MIN.) TREATED (WOLMANIZED) PLYWOOD. (EXTERIOR GRADE)
3. MADE FROM 10 GAUGE ALUMINUM.
4. PROVIDE ACRYLIC ENAMEL FINISH, COLOR TO MATCH TRANSFORMER. (2 COATS)
5. ENCLOSURE SHALL BE NEMA 3R WITH NEOPRENE GASKETING.
6. PADLOCKS:
 - 1-HECO FURNISHED
 - 1-CONTRACTOR FURNISHED, BRASS CORBIN SESAME COMBINATION
7. SHOP FABRICATION DRAWINGS SHALL BE SUBMITTED FOR APPROVAL.
8. LOCATION OF OPENING FOR METER READER TO CORRESPOND WITH LOCATION OF METER.

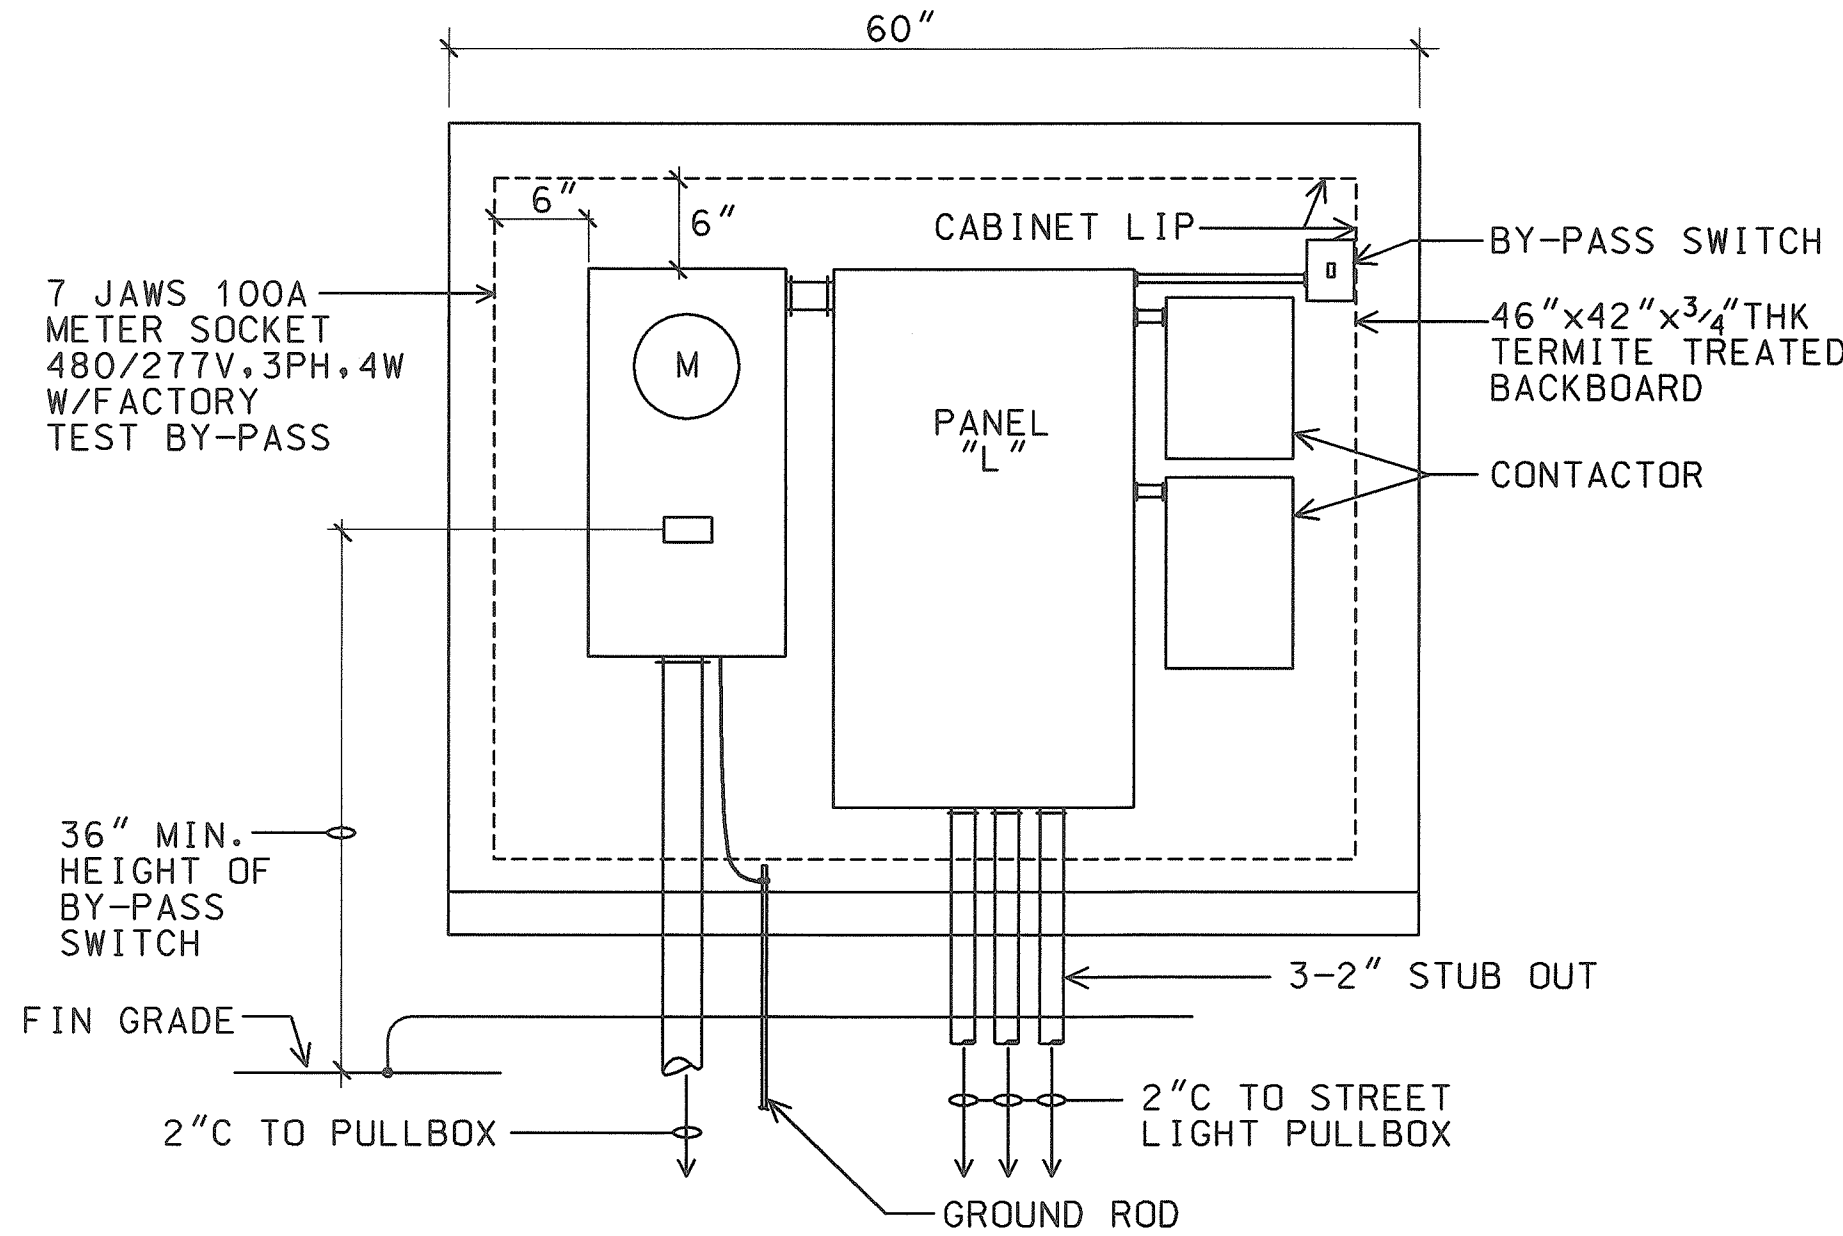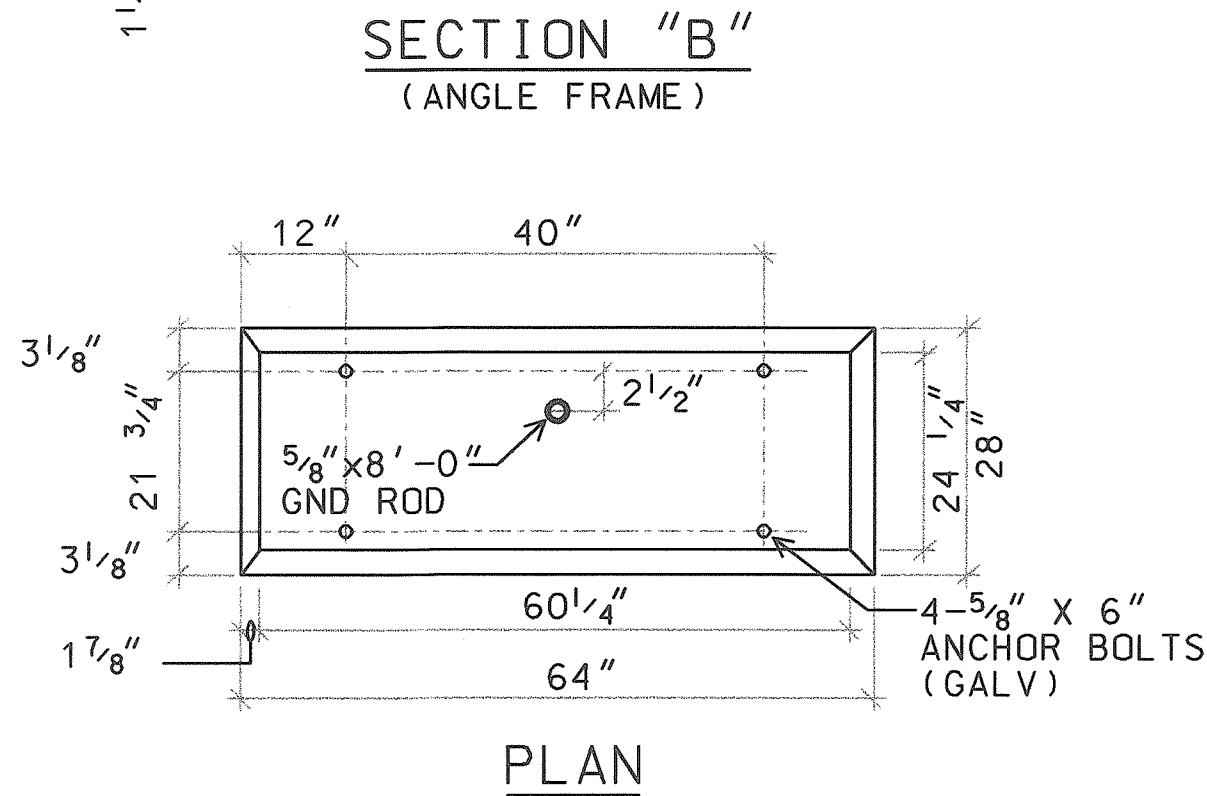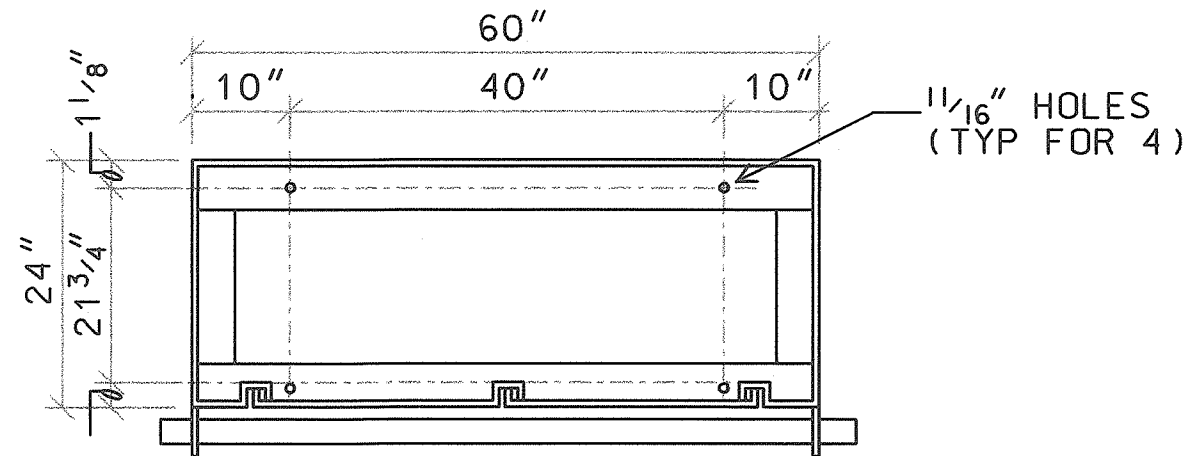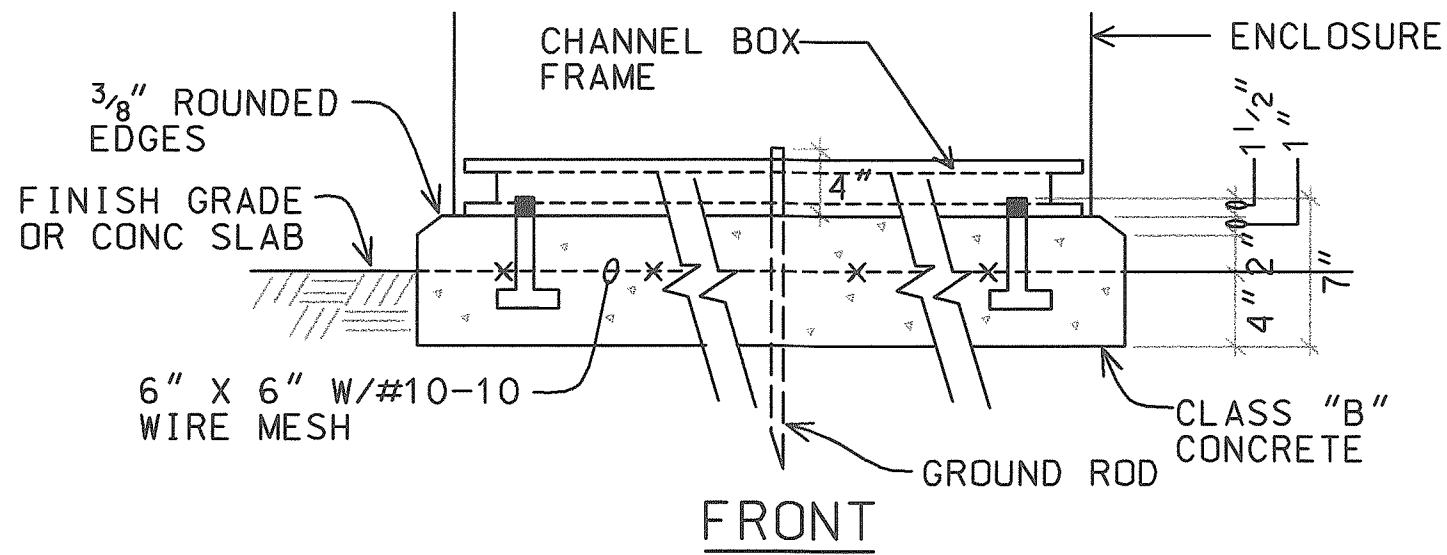

B
E47
NTS
98058KDC

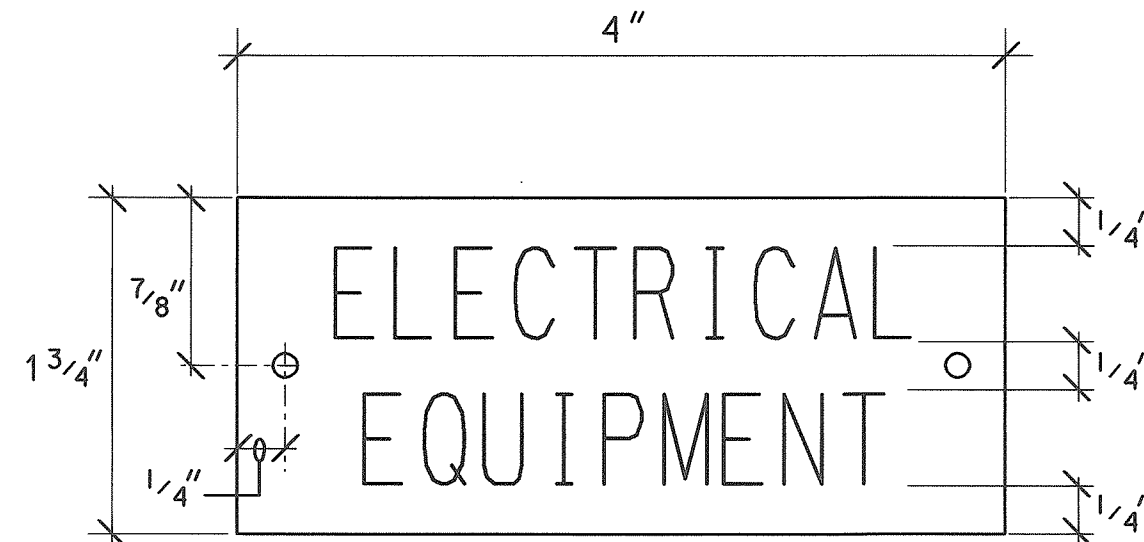


NOTES:

1. USE 2 PLY PLASTIC - BLACK, WHITE.
2. LETTER SIZE SHALL BE 1/2" HIGH AND ENGRAVED 1/16" WIDE, WHITE IN COLOR.
3. ATTACH TO EQUIPMENT ENCLOSURE WITH NO.7 STAINLESS STEEL DRIVE SCREWS.

C
E47
NTS
98058KDD

A
E47
NTS
98058KDE

CONCRETE PAD

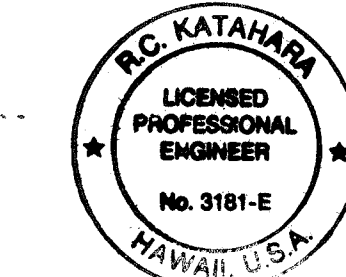


THIS WORK WAS PREPARED BY ME
OR UNDER MY SUPERVISION.
R.C. KATAHARA 11/25/98
MK ENGINEERS, LTD.

STATE OF HAWAII
DEPARTMENT OF TRANSPORTATION
HIGHWAYS DIVISION
METER DETAILS
HIGHWAY LIGHTING SAFETY IMPROVEMENTS
INTERSTATE ROUTE H-1
KEEAUMOKU STREET TO AINAKOA AVE
PROJECT NO. STP-0300(66)
SCALE: AS NOTED DATE: JANUARY 1999
SHEET No. E47 OF 56 SHEETS


AS-BUILT
2/4/03
DATE

FED. ROAD DIST. NO.	STATE	FED. AID PROJ. NO.	FISCAL YEAR	SHEET NO.	TOTAL SHEETS
HAWAII	HAW.	STP-0300(66)	1998		

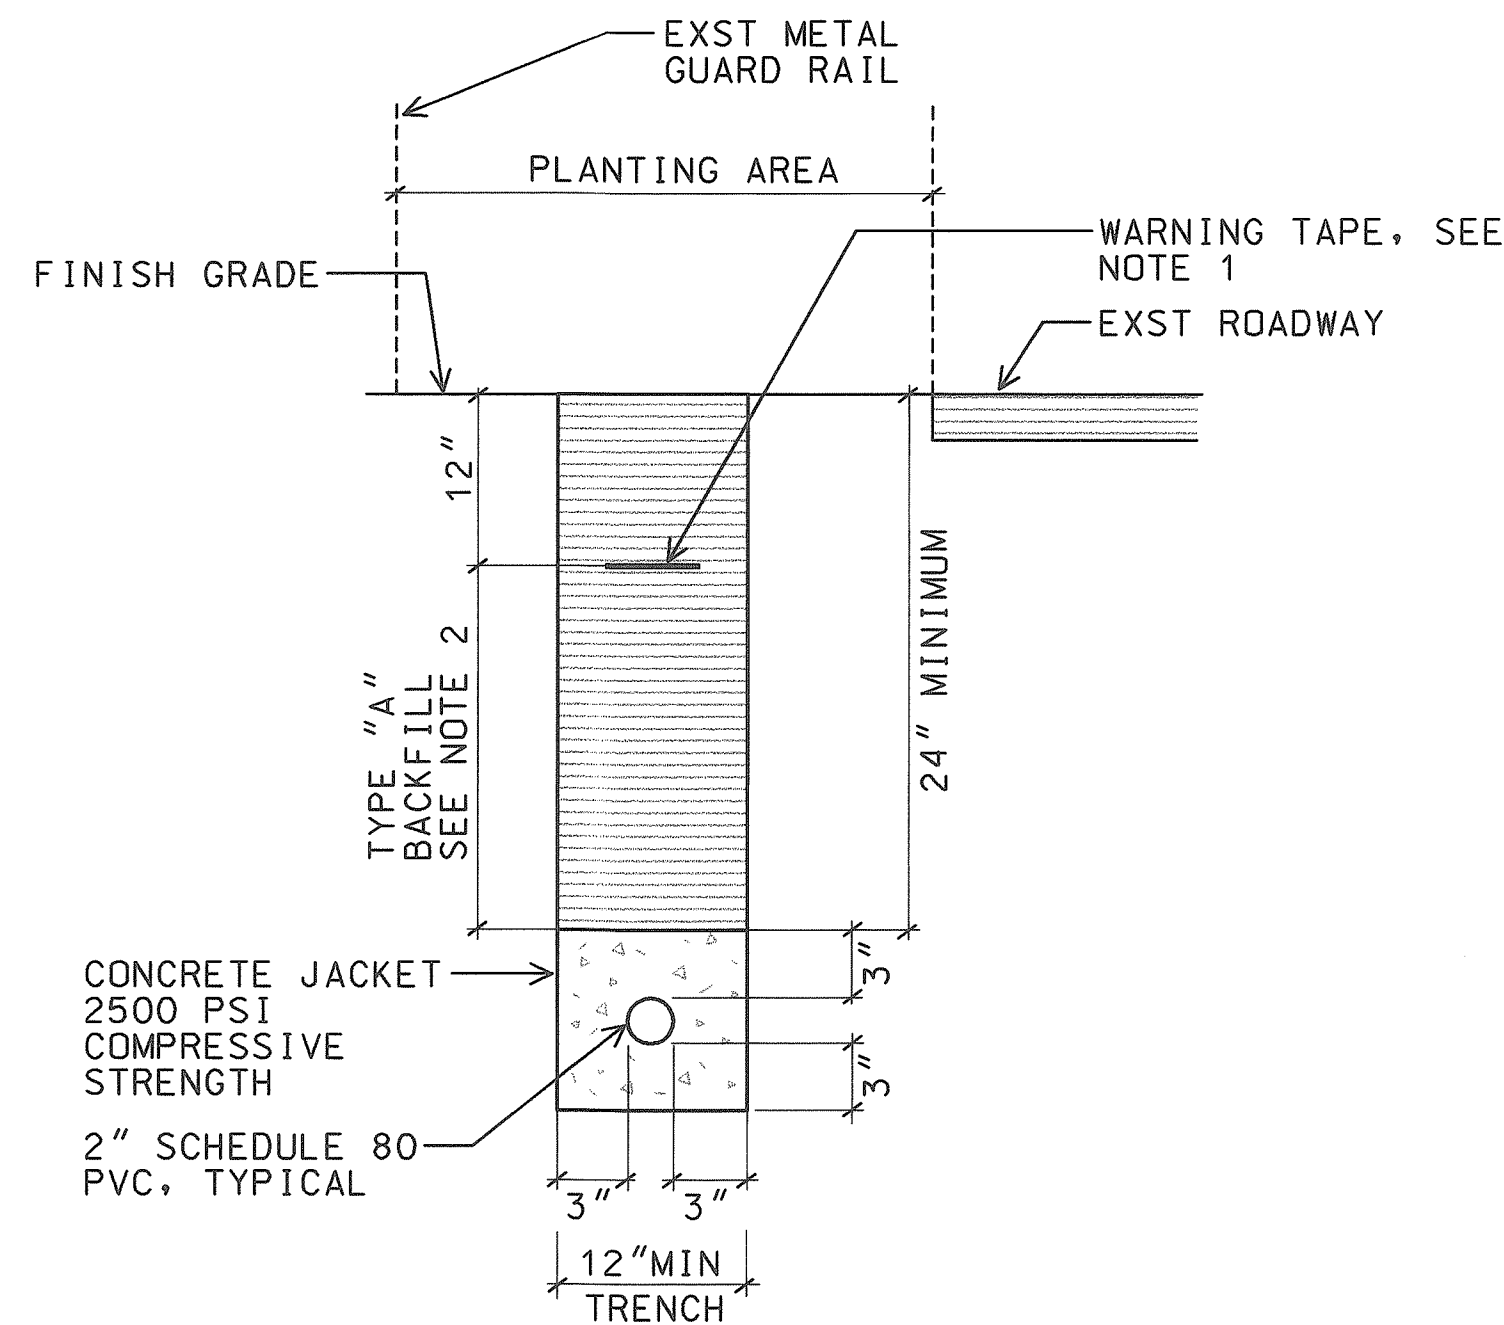


A
E48 CONCRETE ENCASED (NON ROADWAY AREA)
NTS 98058KDA

A1
E48 SIMILAR EXCEPT w/ 2 CONDUITS

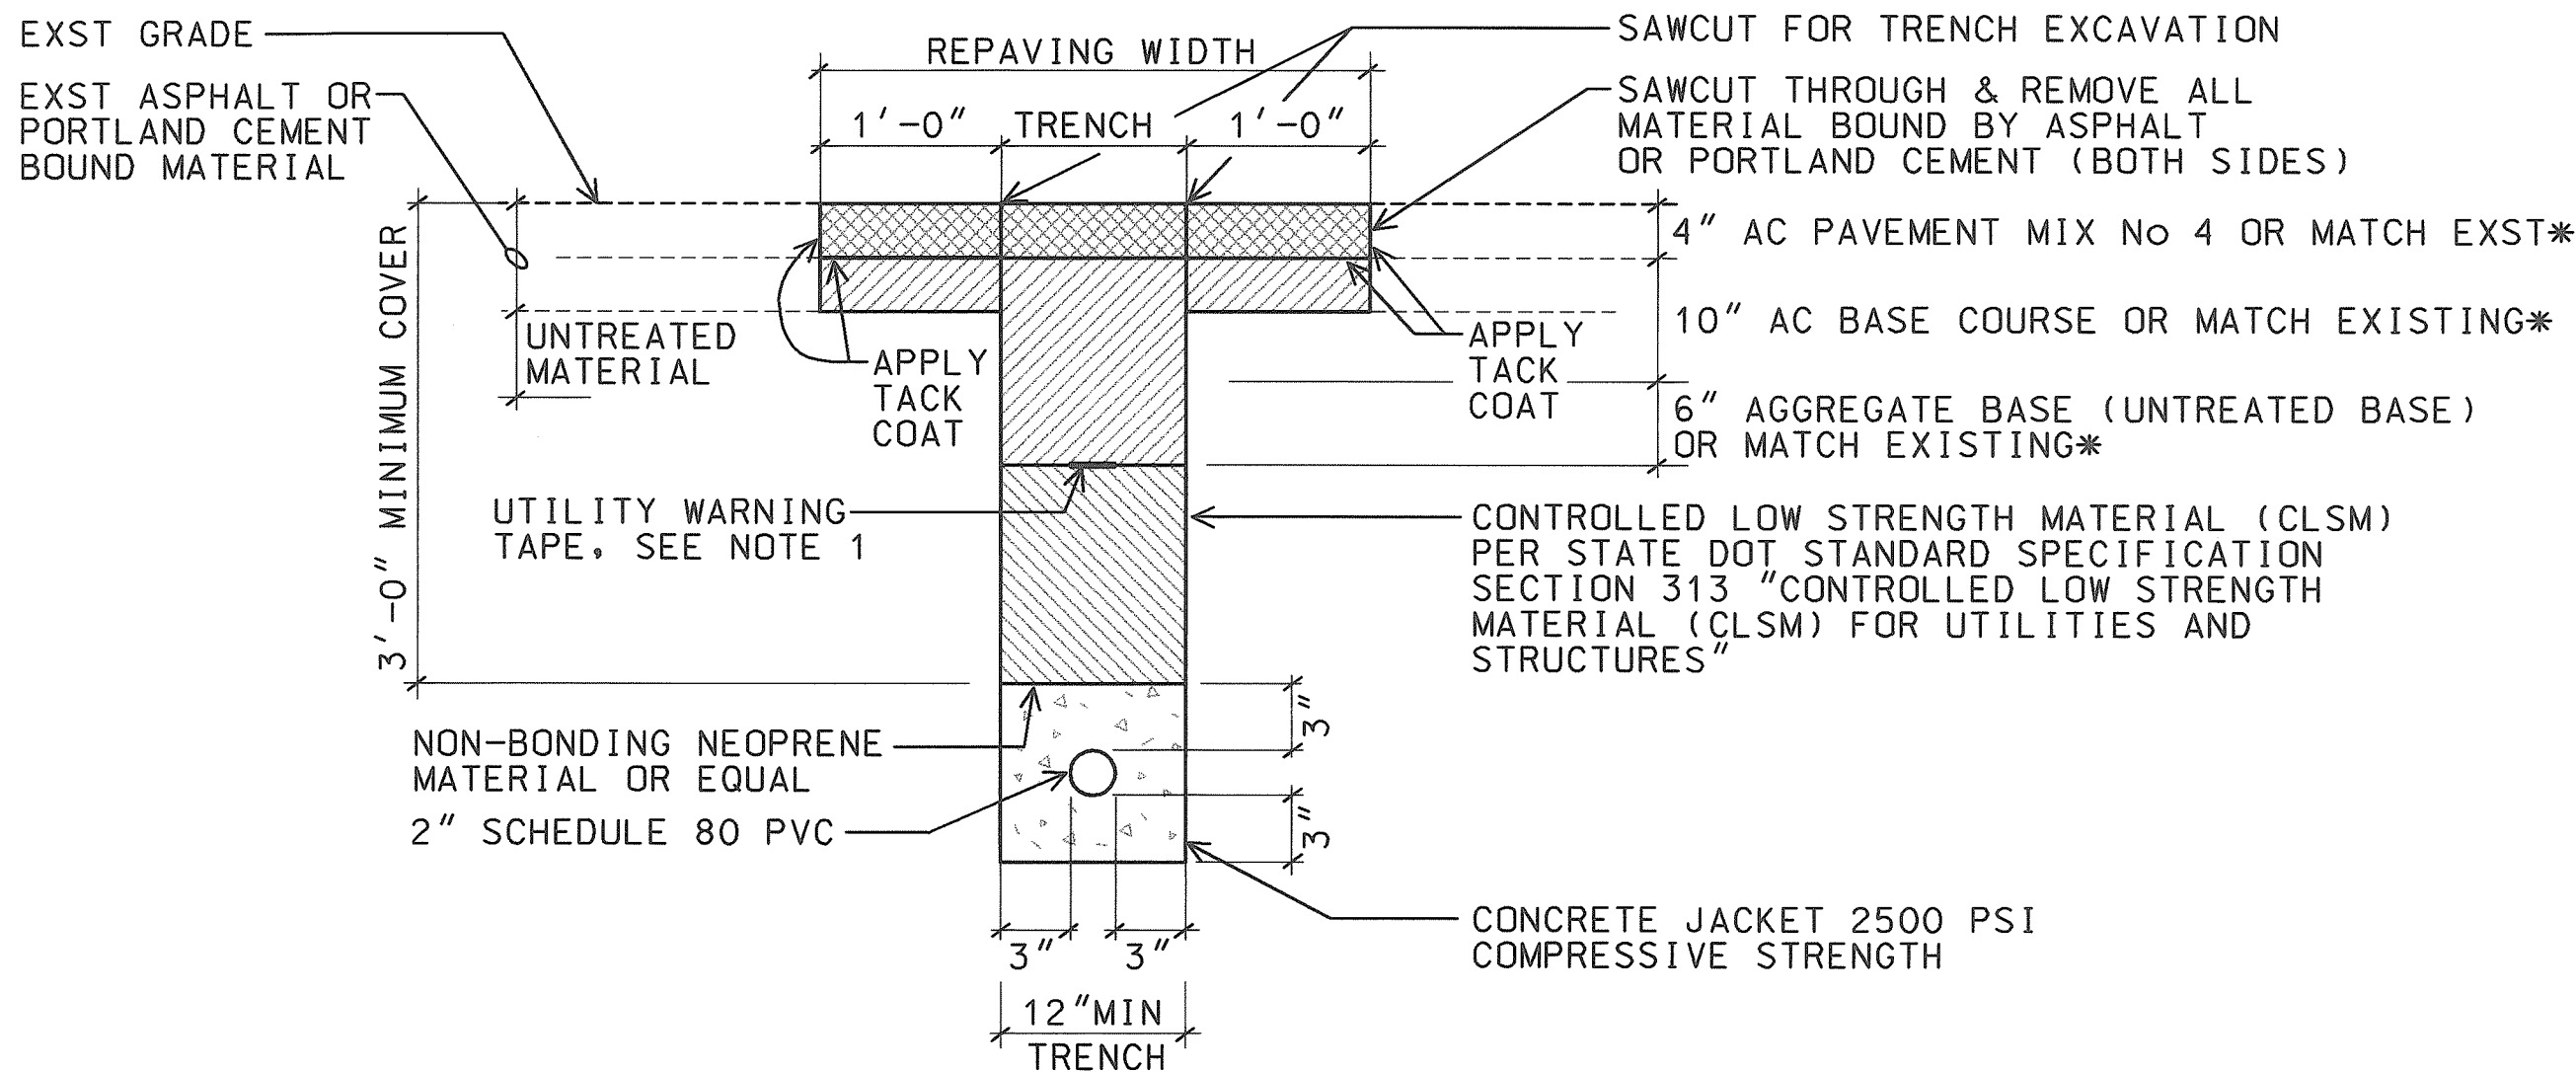


B
E48 TYPICAL PAVEMENT RESTORATION IN STATE HIGHWAY
NTS 98058KDA

B1
E48 SIMILAR EXCEPT w/ 2 CONDUITS

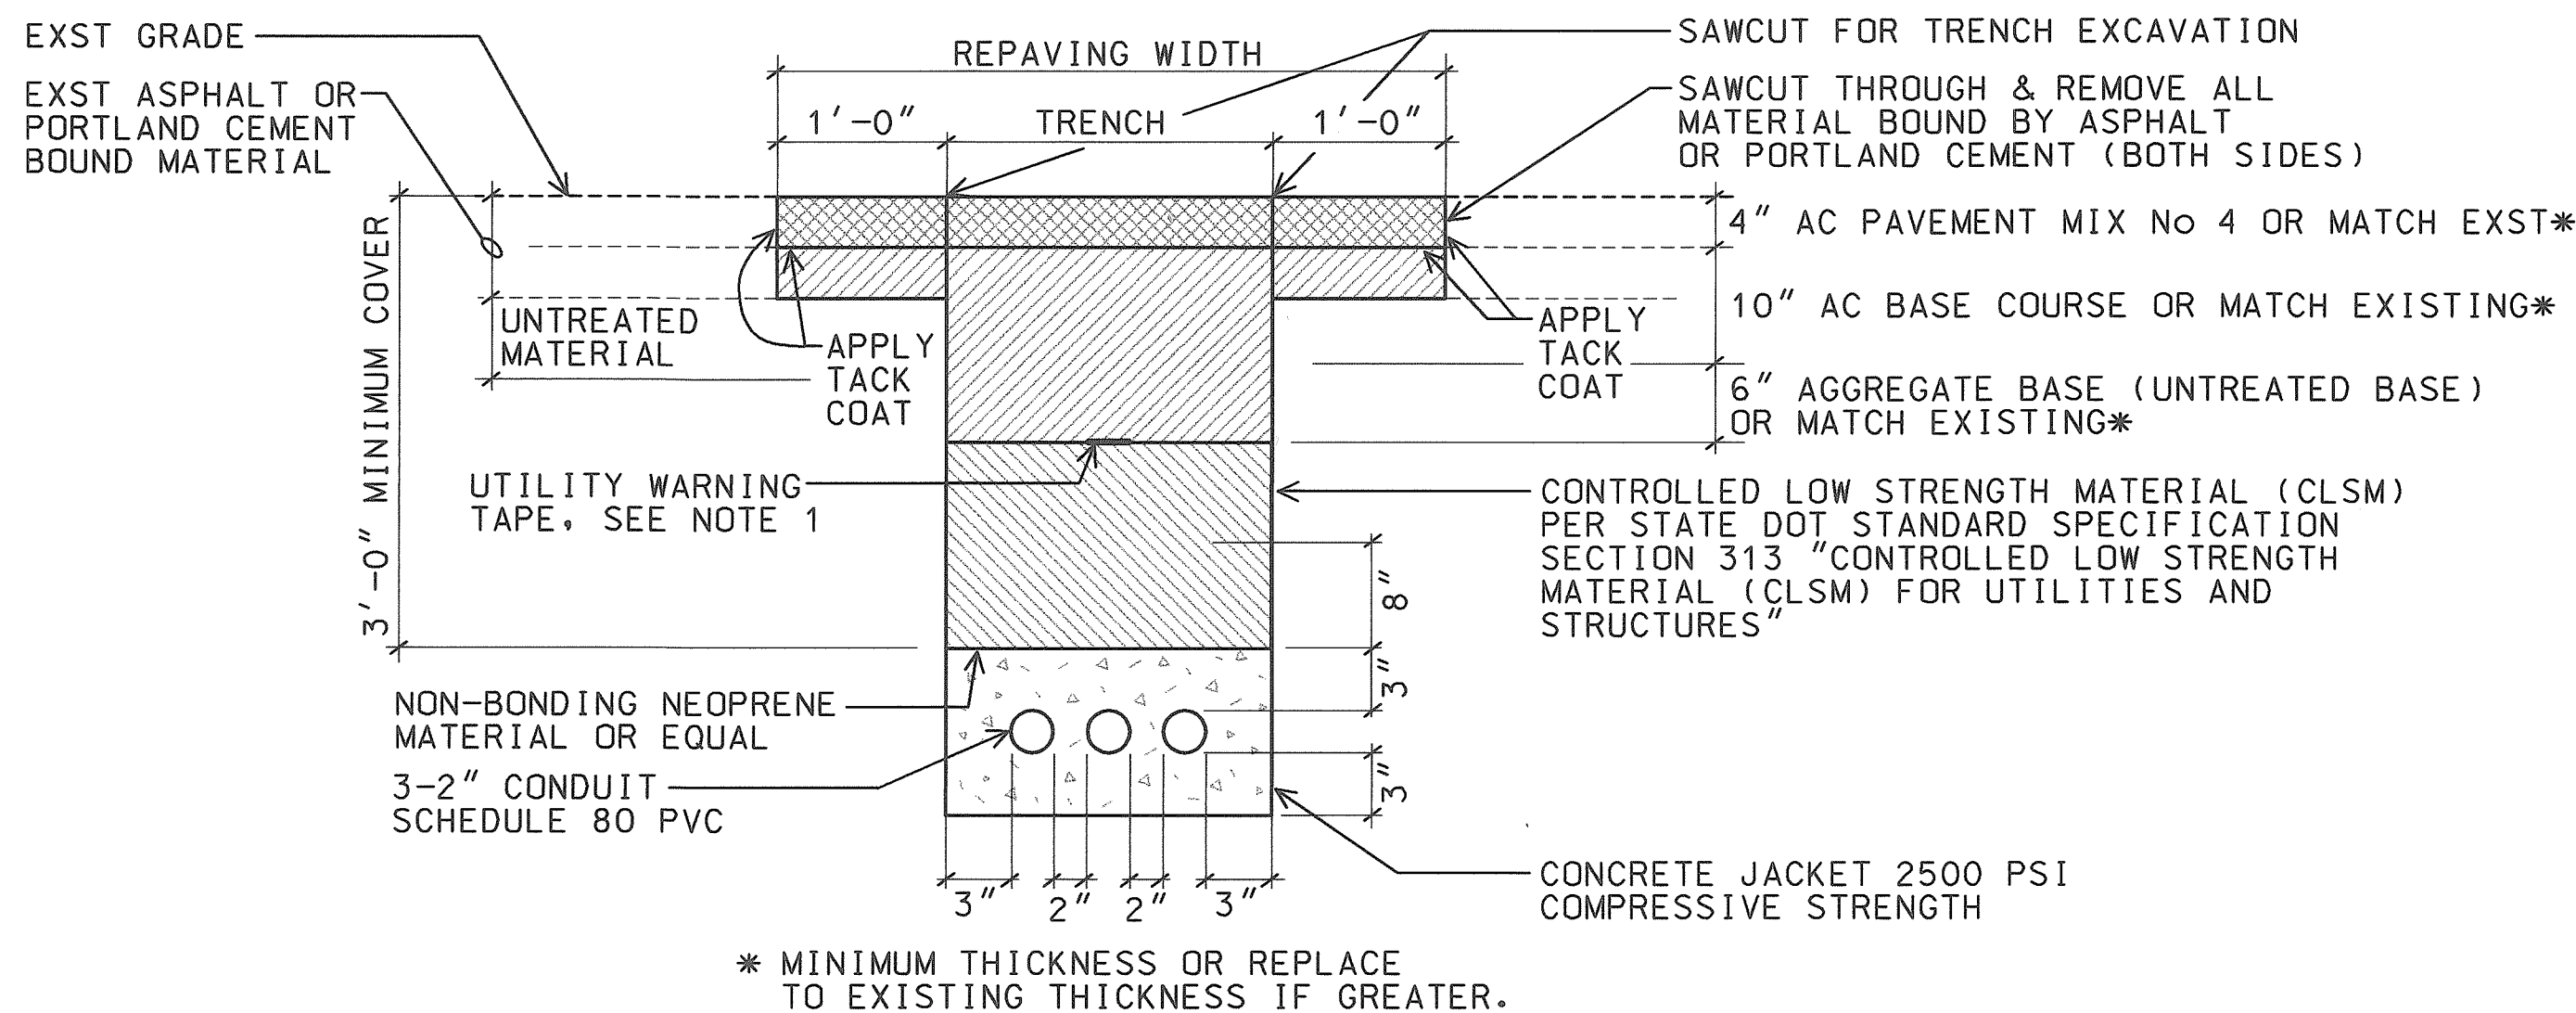


C
E48 TYPICAL PAVEMENT RESTORATION IN STATE HIGHWAY
NTS 98058KDA

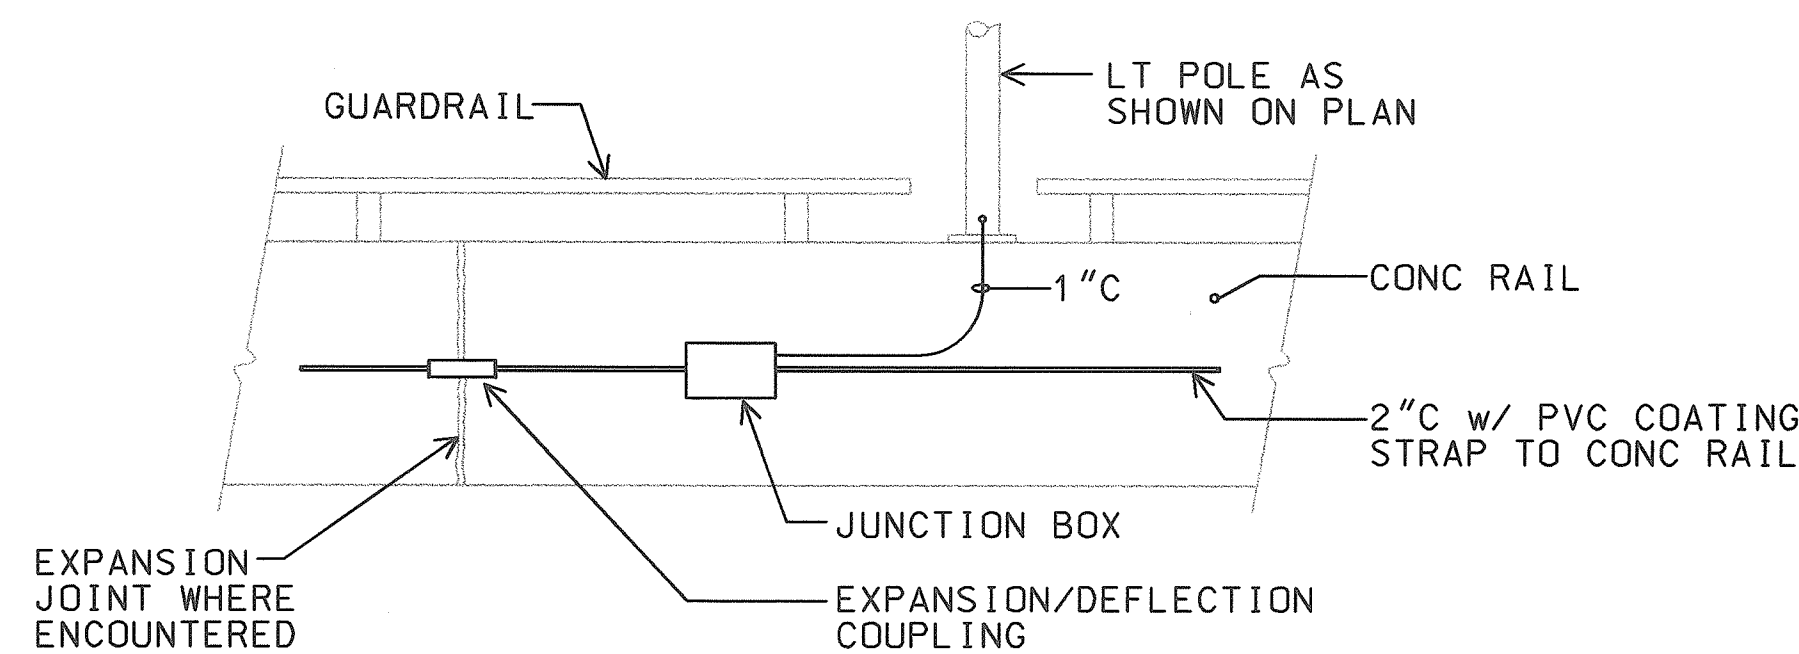

D
E48 JUNCTION BOX MOUNTING DETAIL
NOT TO SCALE 98058KEL

NOTES:


- 8 MIL THICK YELLOW COLORED PLASTIC WARNING TAPE 3" WIDE, ENTIRE LENGTH OF DUCT. TAPE TO HAVE CONTINUOUS METALLIC BACKING AND CORROSION RESISTANT FOIL CORE. WARNING AND IDENTIFICATION TO BE IMPRINTED ON TAPE AND SHALL READ "CAUTION BURIED ELECTRIC CABLE BELOW". MESSAGE SHALL BE REPEATED APPROXIMATELY EVERY TEN FEET.
- TYPE "A" BACKFILL: BEACH SAND, EARTH OR EARTH AND GRAVEL USED. THE MAXIMUM ROCK SIZE SHALL BE 1" AND THE MIXTURE SHALL CONTAIN NOT MORE THAN 50% BY VOLUME OF ROCK PARTICLES.

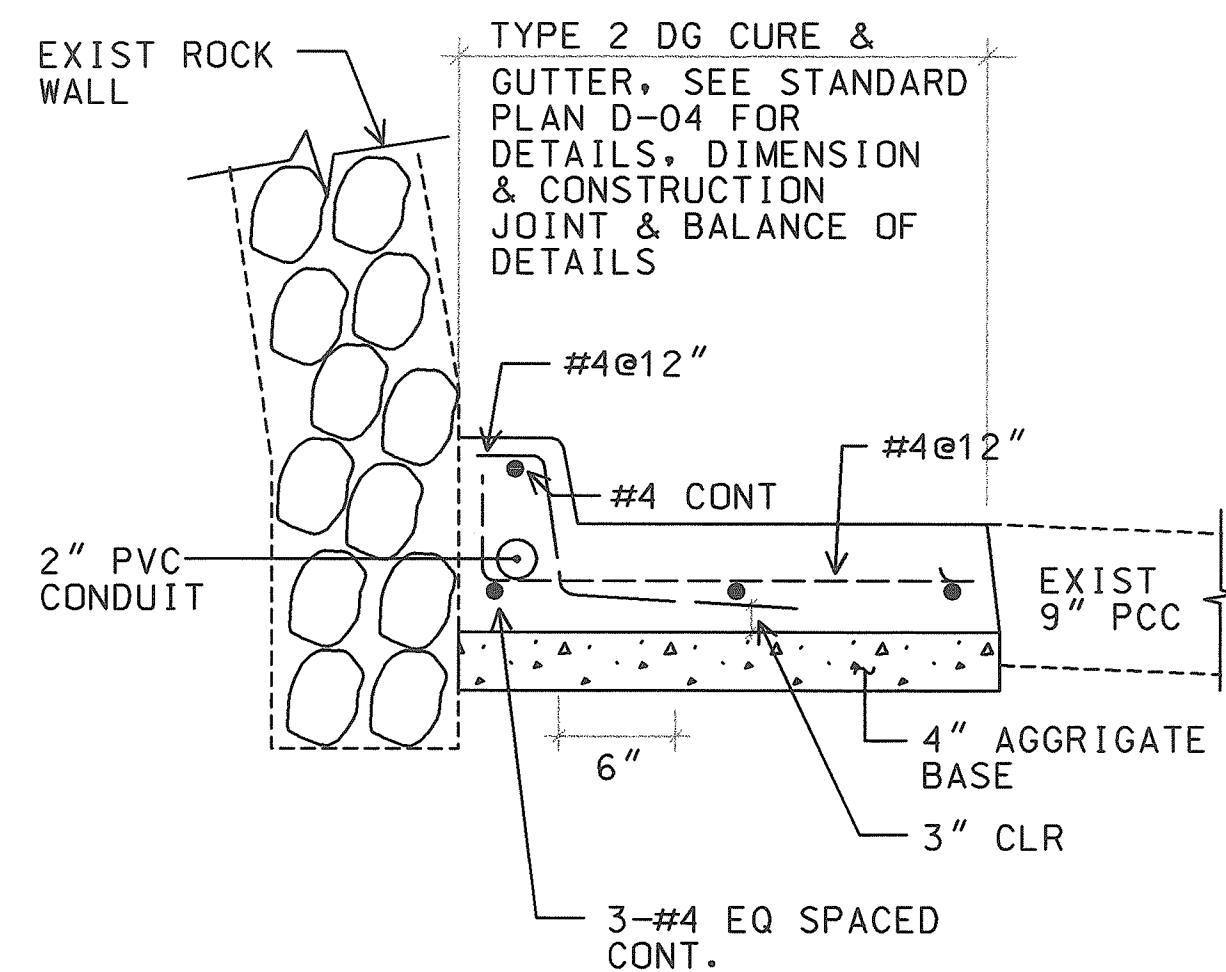

E
E48 TYPE 2DG CURB & GUTTER
NOT TO SCALE 98058KDA

H-1 B/L STA. 109+00 TO 132+00
IB & OB.




AS-BUILT
4/4/03
DATE

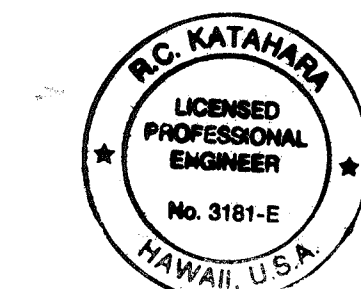

THIS WORK WAS PREPARED BY ME
OR UNDER MY SUPERVISION.
R.C. KATAHARA 4/25/98
MK ENGINEERS, LTD.

STATE OF HAWAII
DEPARTMENT OF TRANSPORTATION
HIGHWAYS DIVISION
DUCT SECTIONS
HIGHWAY LIGHTING SAFETY IMPROVEMENTS
INTERSTATE ROUTE H-1
KEEAUMOKU STREET TO AINAKOA AVE
PROJECT NO. STP-0300(66)
SCALE: AS NOTED DATE: JANUARY 1999
SHEET No. E48 OF 56 SHEETS


FED. ROAD DIST. NO.	STATE	FED. AID PROJ. NO.	FISCAL YEAR	SHEET NO.	TOTAL SHEETS
HAWAII	HAW.	STP-0300(66)	1998		

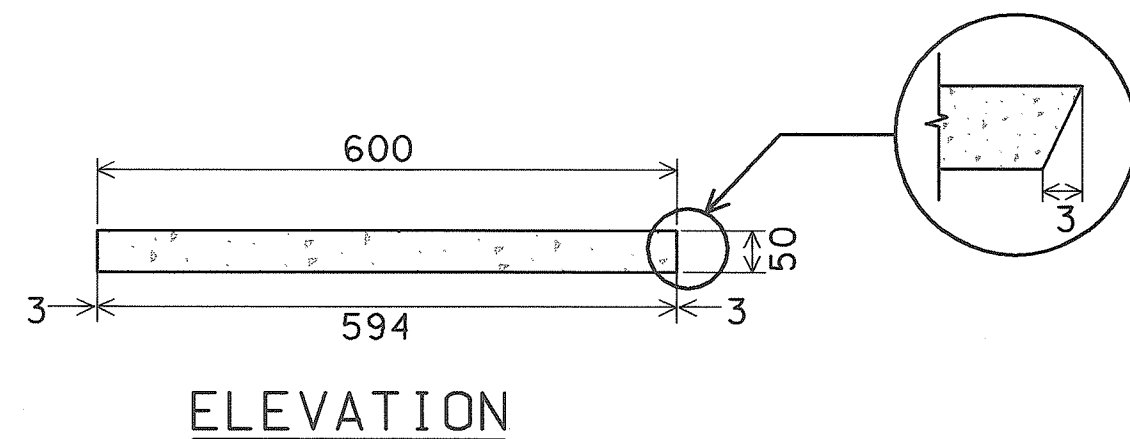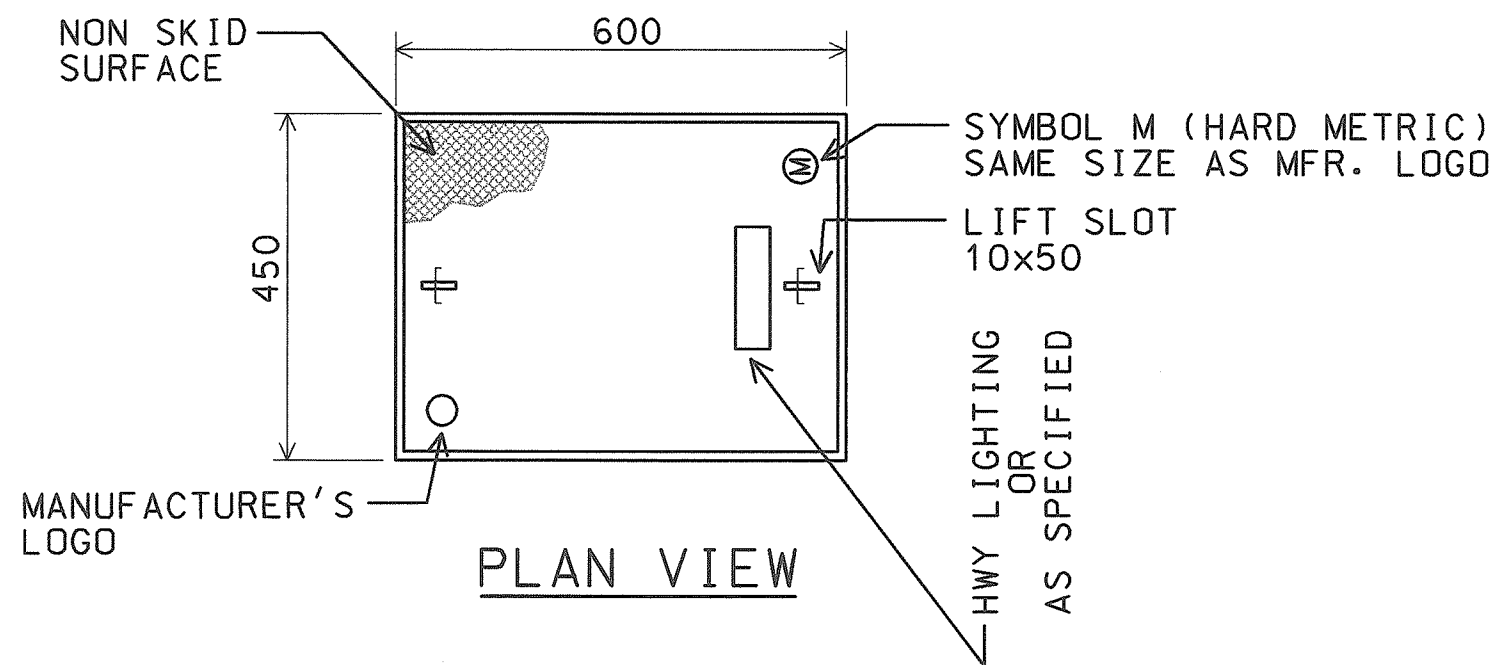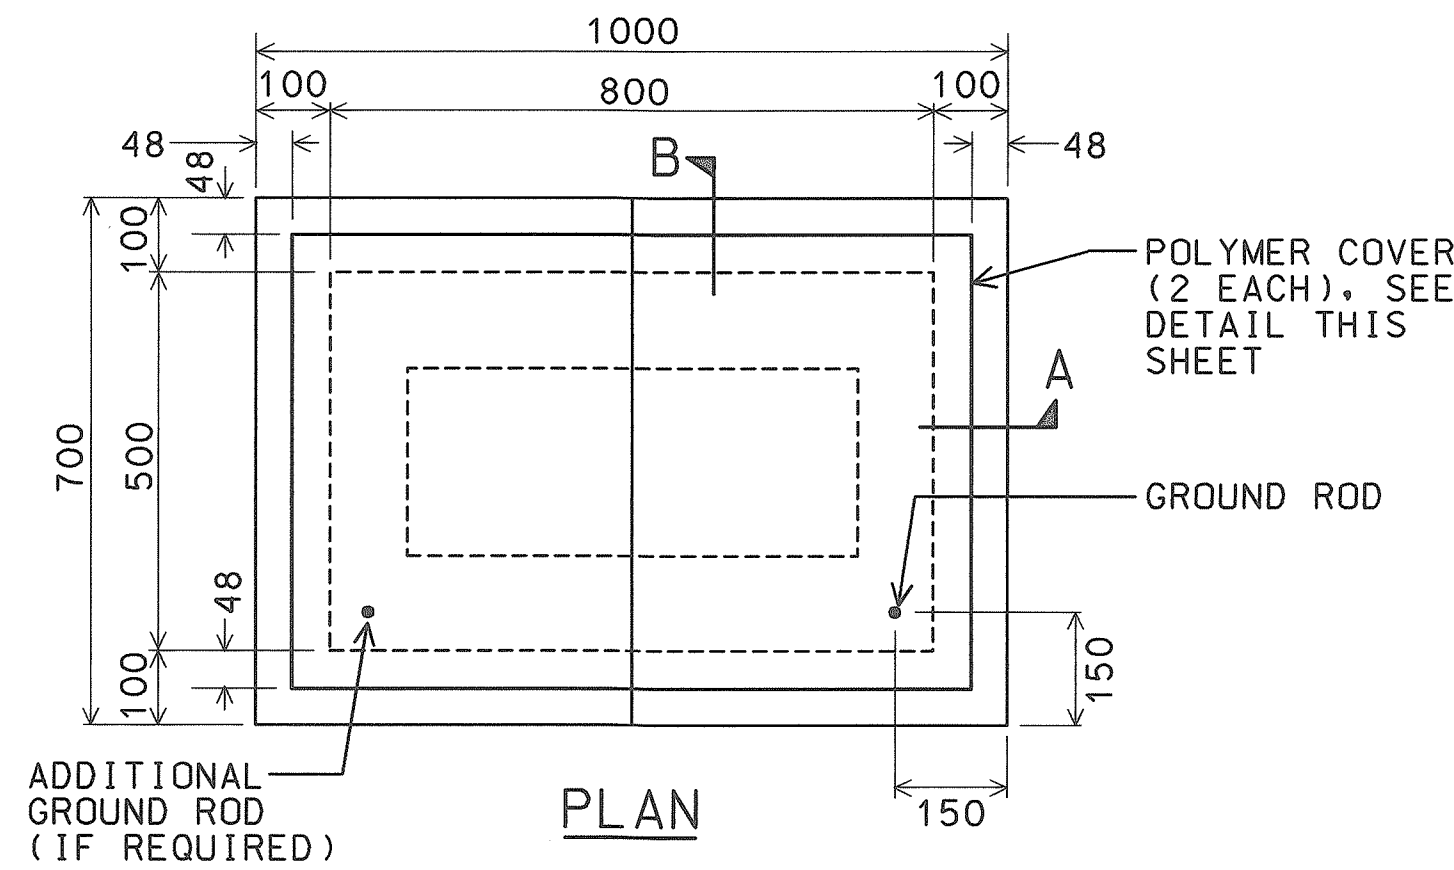


POLYMER CONCRETE COVER
NOT TO SCALE 98058KDE

GENERAL NOTES:


1. ALL PRE-CAST CONCRETE PULLBOXES SHALL BE MANUFACTURED IN TWO PIECES.
2. THE PULLBOX WITH COVER SHALL BE CAPABLE OF SUPPORTING AN MS 18 LOADING.
3. THE MAXIMUM WEIGHT OF THE PULLBOX COVER SHALL NOT EXCEED 27 KILOGRAMS.
4. THE OPENINGS FOR THE CONDUITS ON ALL PULLBOXES SHALL BE PRE-CAST CONCRETE KNOCKOUTS.
5. AFTER INSTALLING THE CONDUITS IN THE OPENINGS OF THE PULLBOXES, THE CONTRACTOR SHALL FILL THE EXCESS OPENING IN THE PRE-CAST KNOCKOUTS WITH CONCRETE MORTAR.
6. PRIOR TO INSTALLING THE PULLBOXES, THE CONTRACTOR SHALL LEVEL THE BOTTOM OF THE TRENCH AND ACHIEVE A MINIMUM OF 95% RELATIVE COMPACTION OF THE BOTTOM OF THE TRENCH.
7. ALL CONCRETE SHALL BE CLASS A (25MPa, MINIMUM).
8. REBARS SHALL BE GRADE 300 AND ALL LAPPED SPLICES SHALL BE 360mm MINIMUM.
10. THE #57 OR #67 SIZE AGGREGATE SHALL CONFORM TO LATEST VERSION OF AASHTO M43 (ASTM D 448).

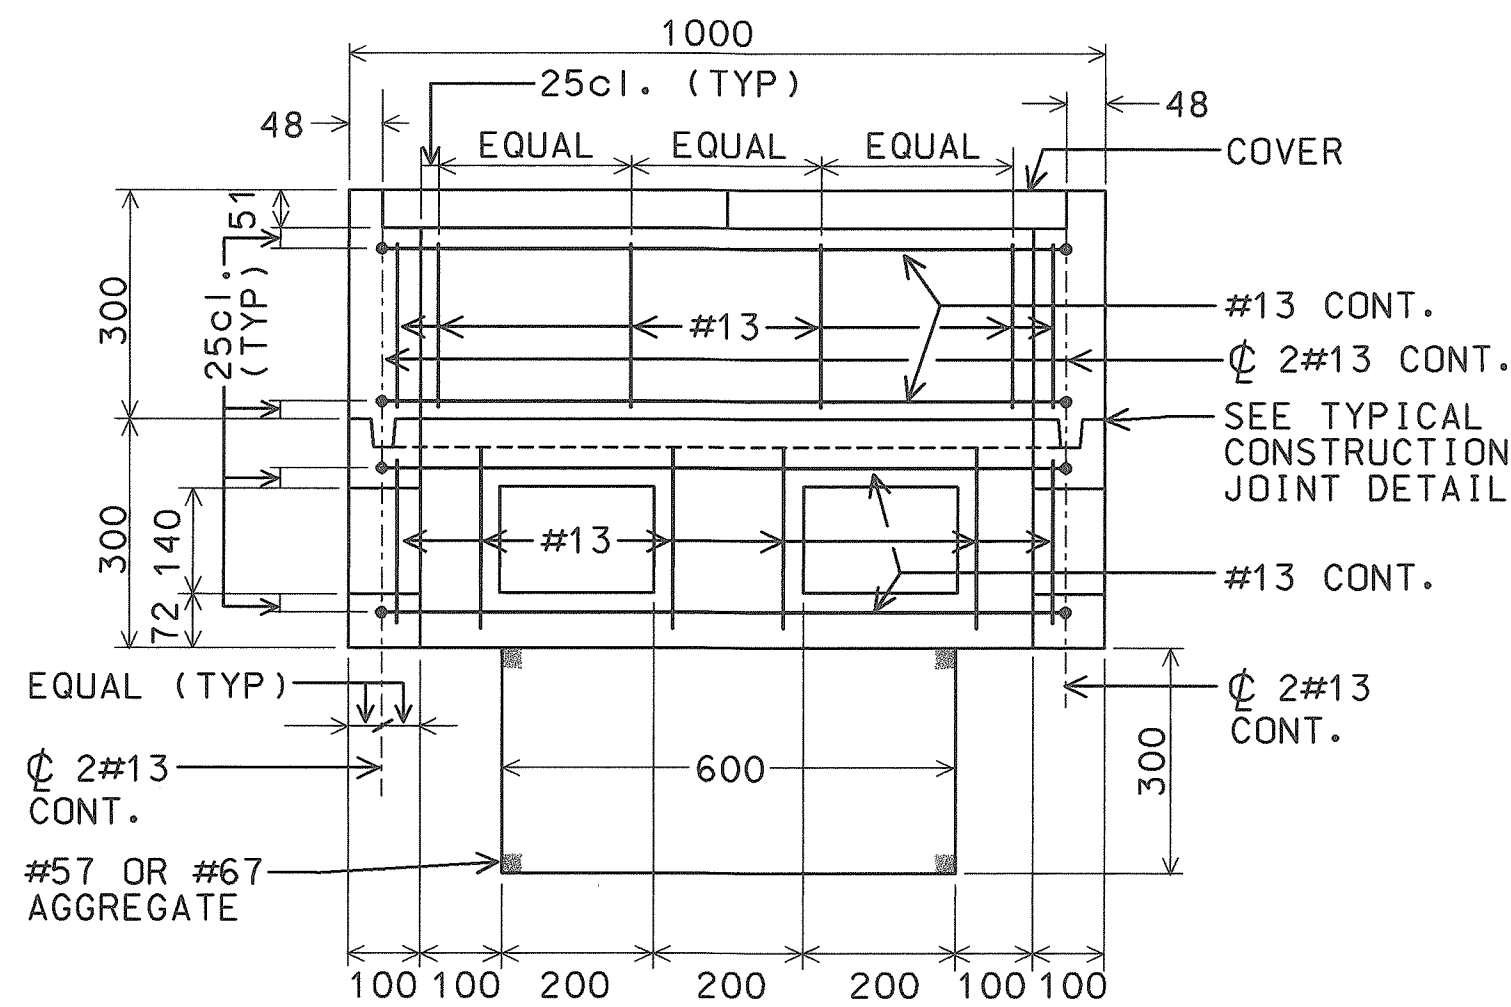

SECTION A-A

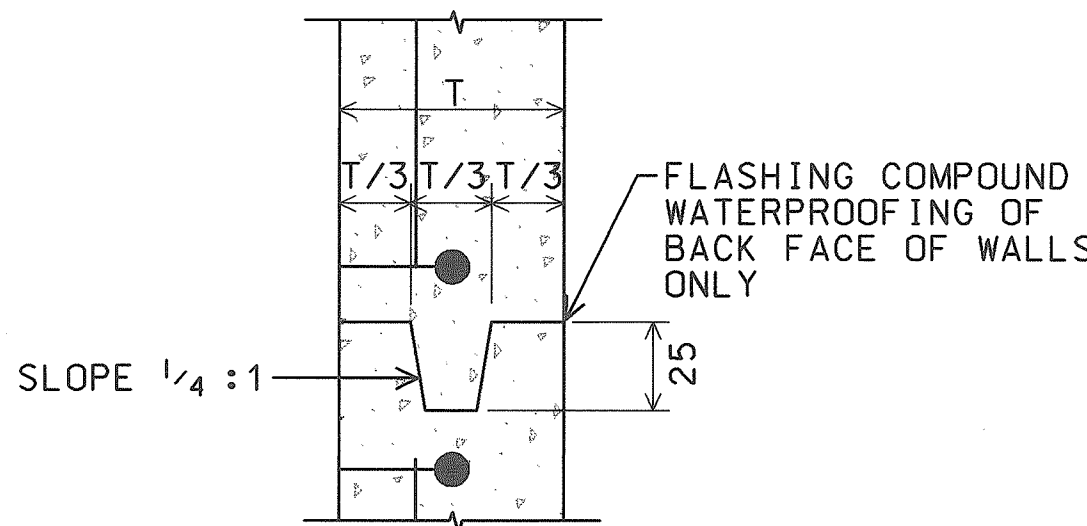


TYPICAL CONSTRUCTION JOINT DETAIL
NOT TO SCALE 98058KDE

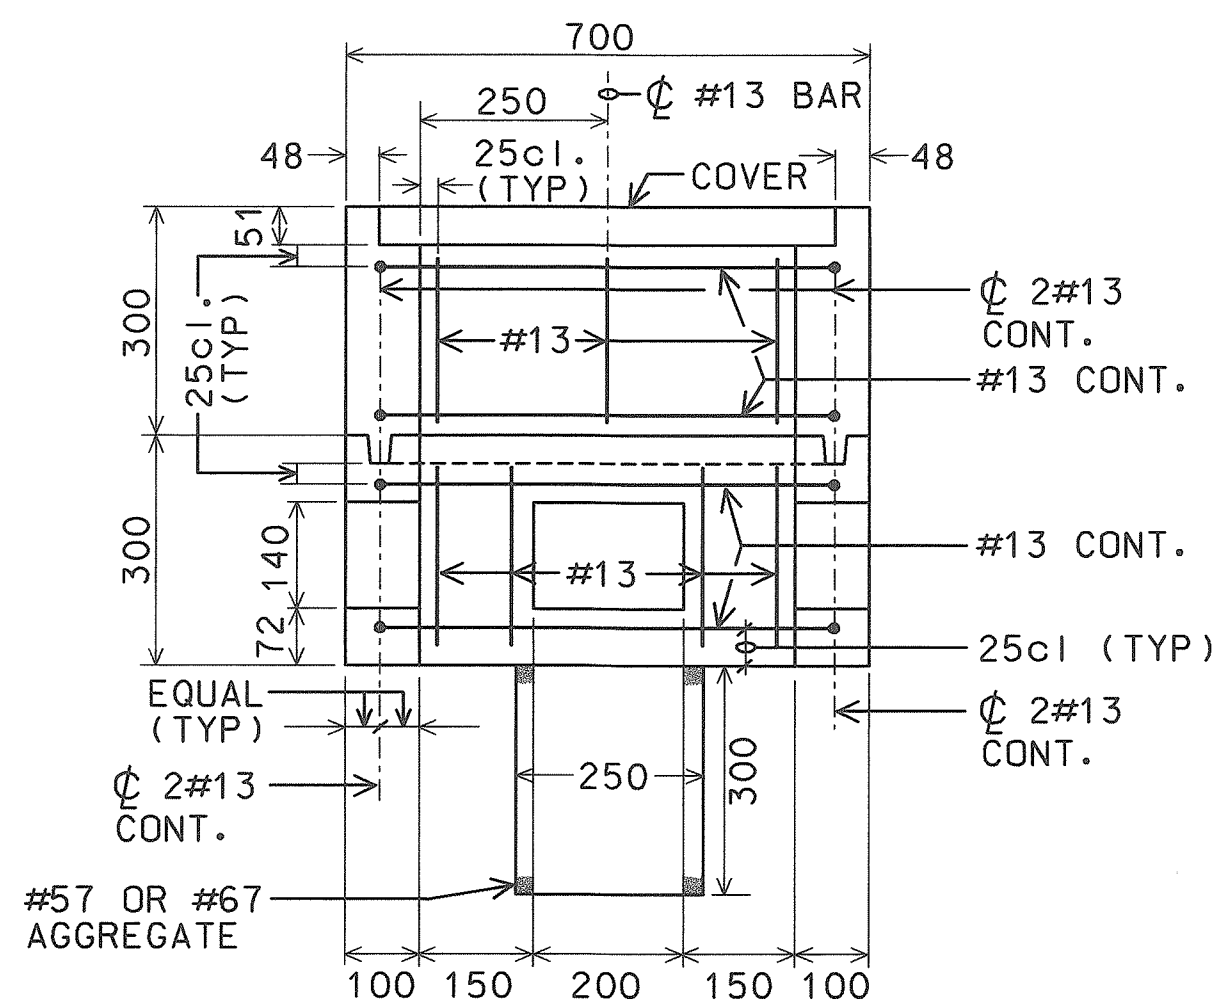


SECTION B-B


A TYPE "B" PULLBOX (OLD TYPE "C")
E49 SCALE: 1:100 98058KDE

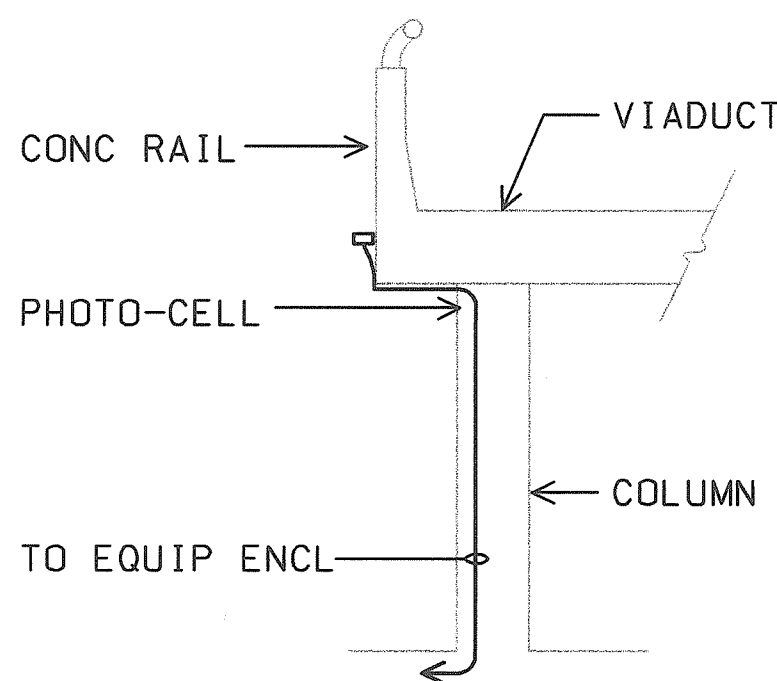

C PHOTO-CELL MTG DETAIL
E49 NOT TO SCALE 98058KEP

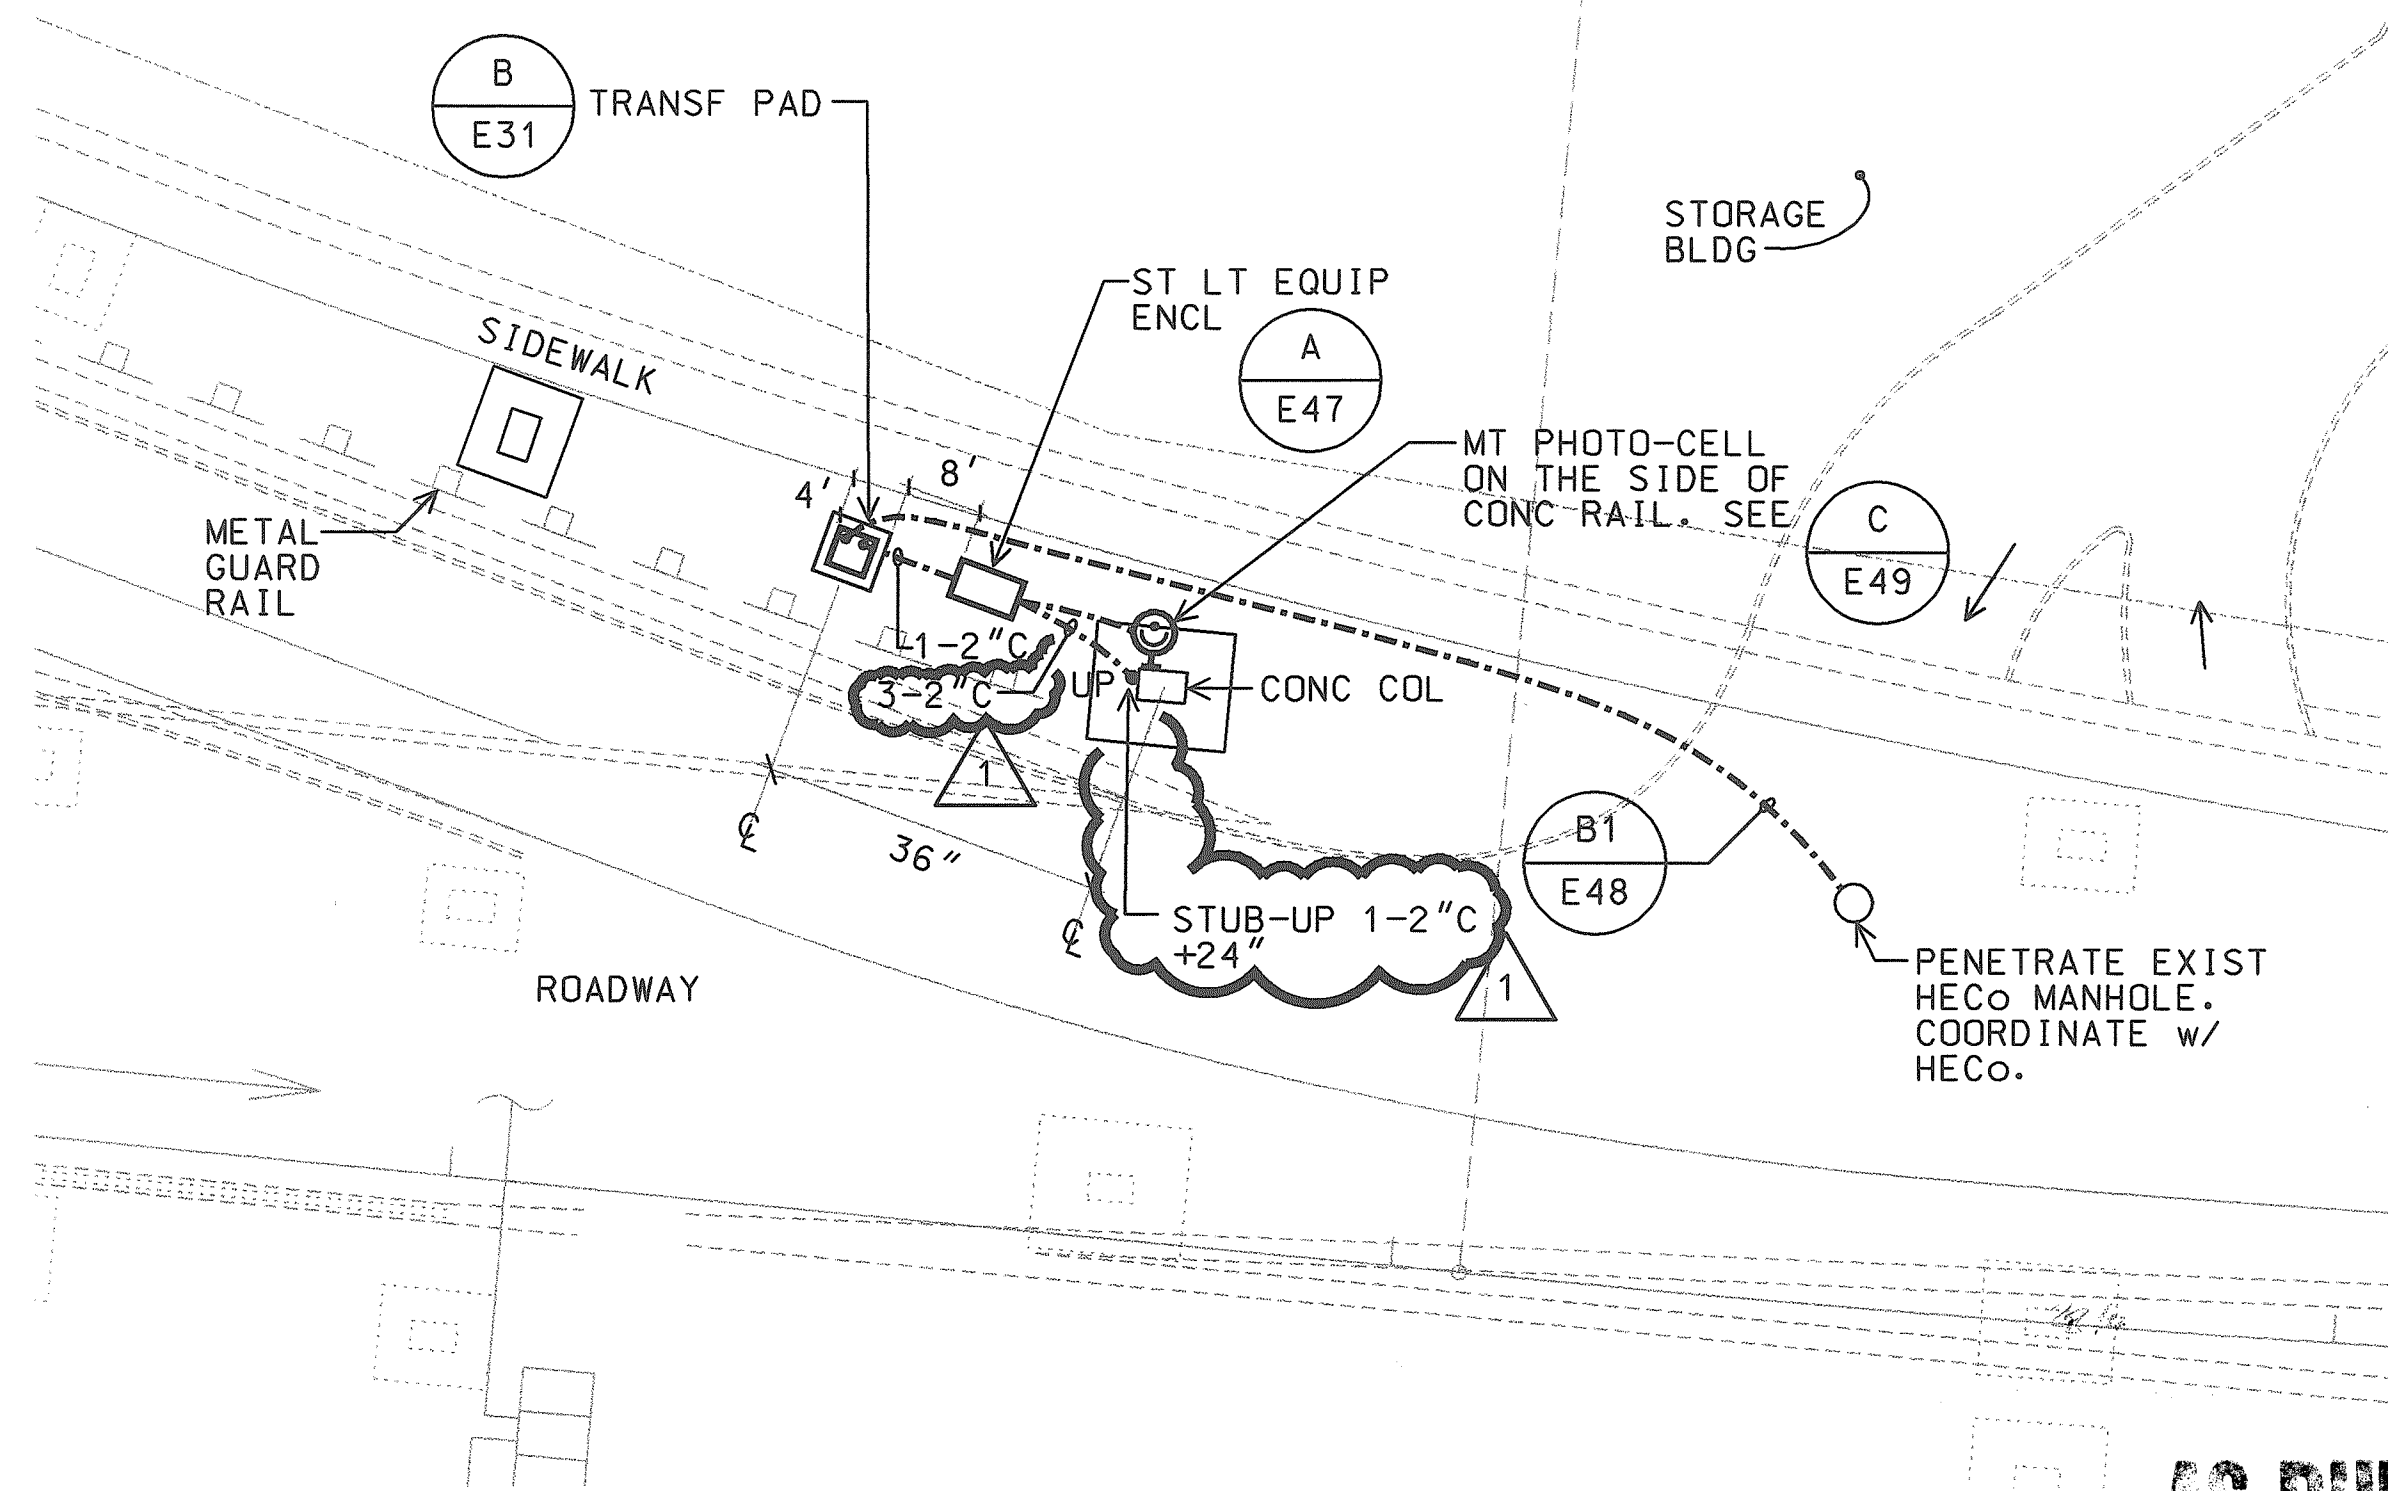

B TRANSF PAD & ENCL. PLAN
E49 SCALE: 1" = 20' 98058KDE


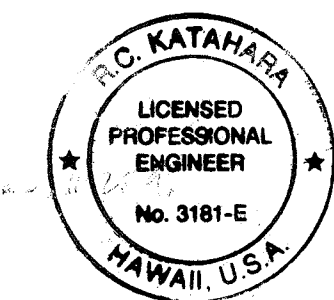


THIS WORK WAS PREPARED BY ME
OR UNDER MY SUPERVISION.
R.C. KATAHARA 4/25/98
MK ENGINEERS, LTD.

DATE	REV	DESCRIPTION
8/16/99	1	ADD 1-2"C FOR FUT. UNDERPASS LTG
STATE OF HAWAII DEPARTMENT OF TRANSPORTATION HIGHWAYS DIVISION PULLBOX DETAILS HIGHWAY LIGHTING SAFETY IMPROVEMENTS INTERSTATE ROUTE H-1 KEEAUMOKU STREET TO AINAKOA AVE PROJECT NO. STP-0300(66) SCALE: AS NOTED DATE: JANUARY 1999 SHEET No. E49 OF 56 SHEETS		


C0-E49

FED. ROAD DIST. NO.	STATE	FED. AID PROJ. NO.	FISCAL YEAR	SHEET NO.	TOTAL SHEETS
HAWAII	HAW.	STP-0300(66)	1998		

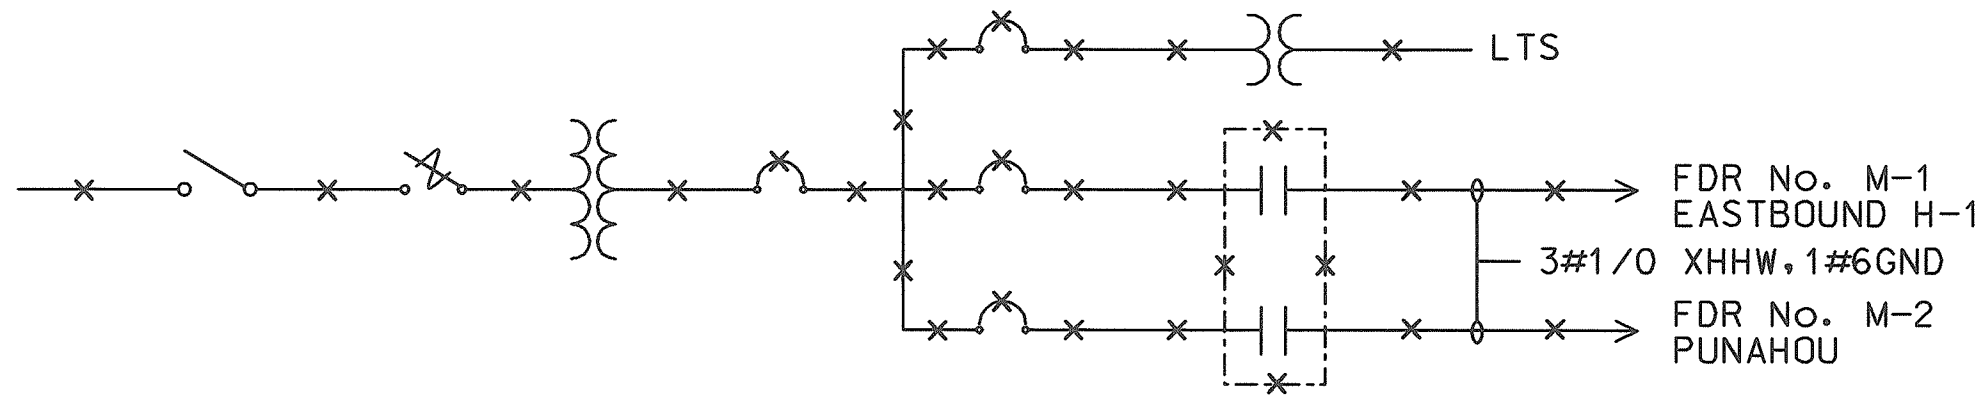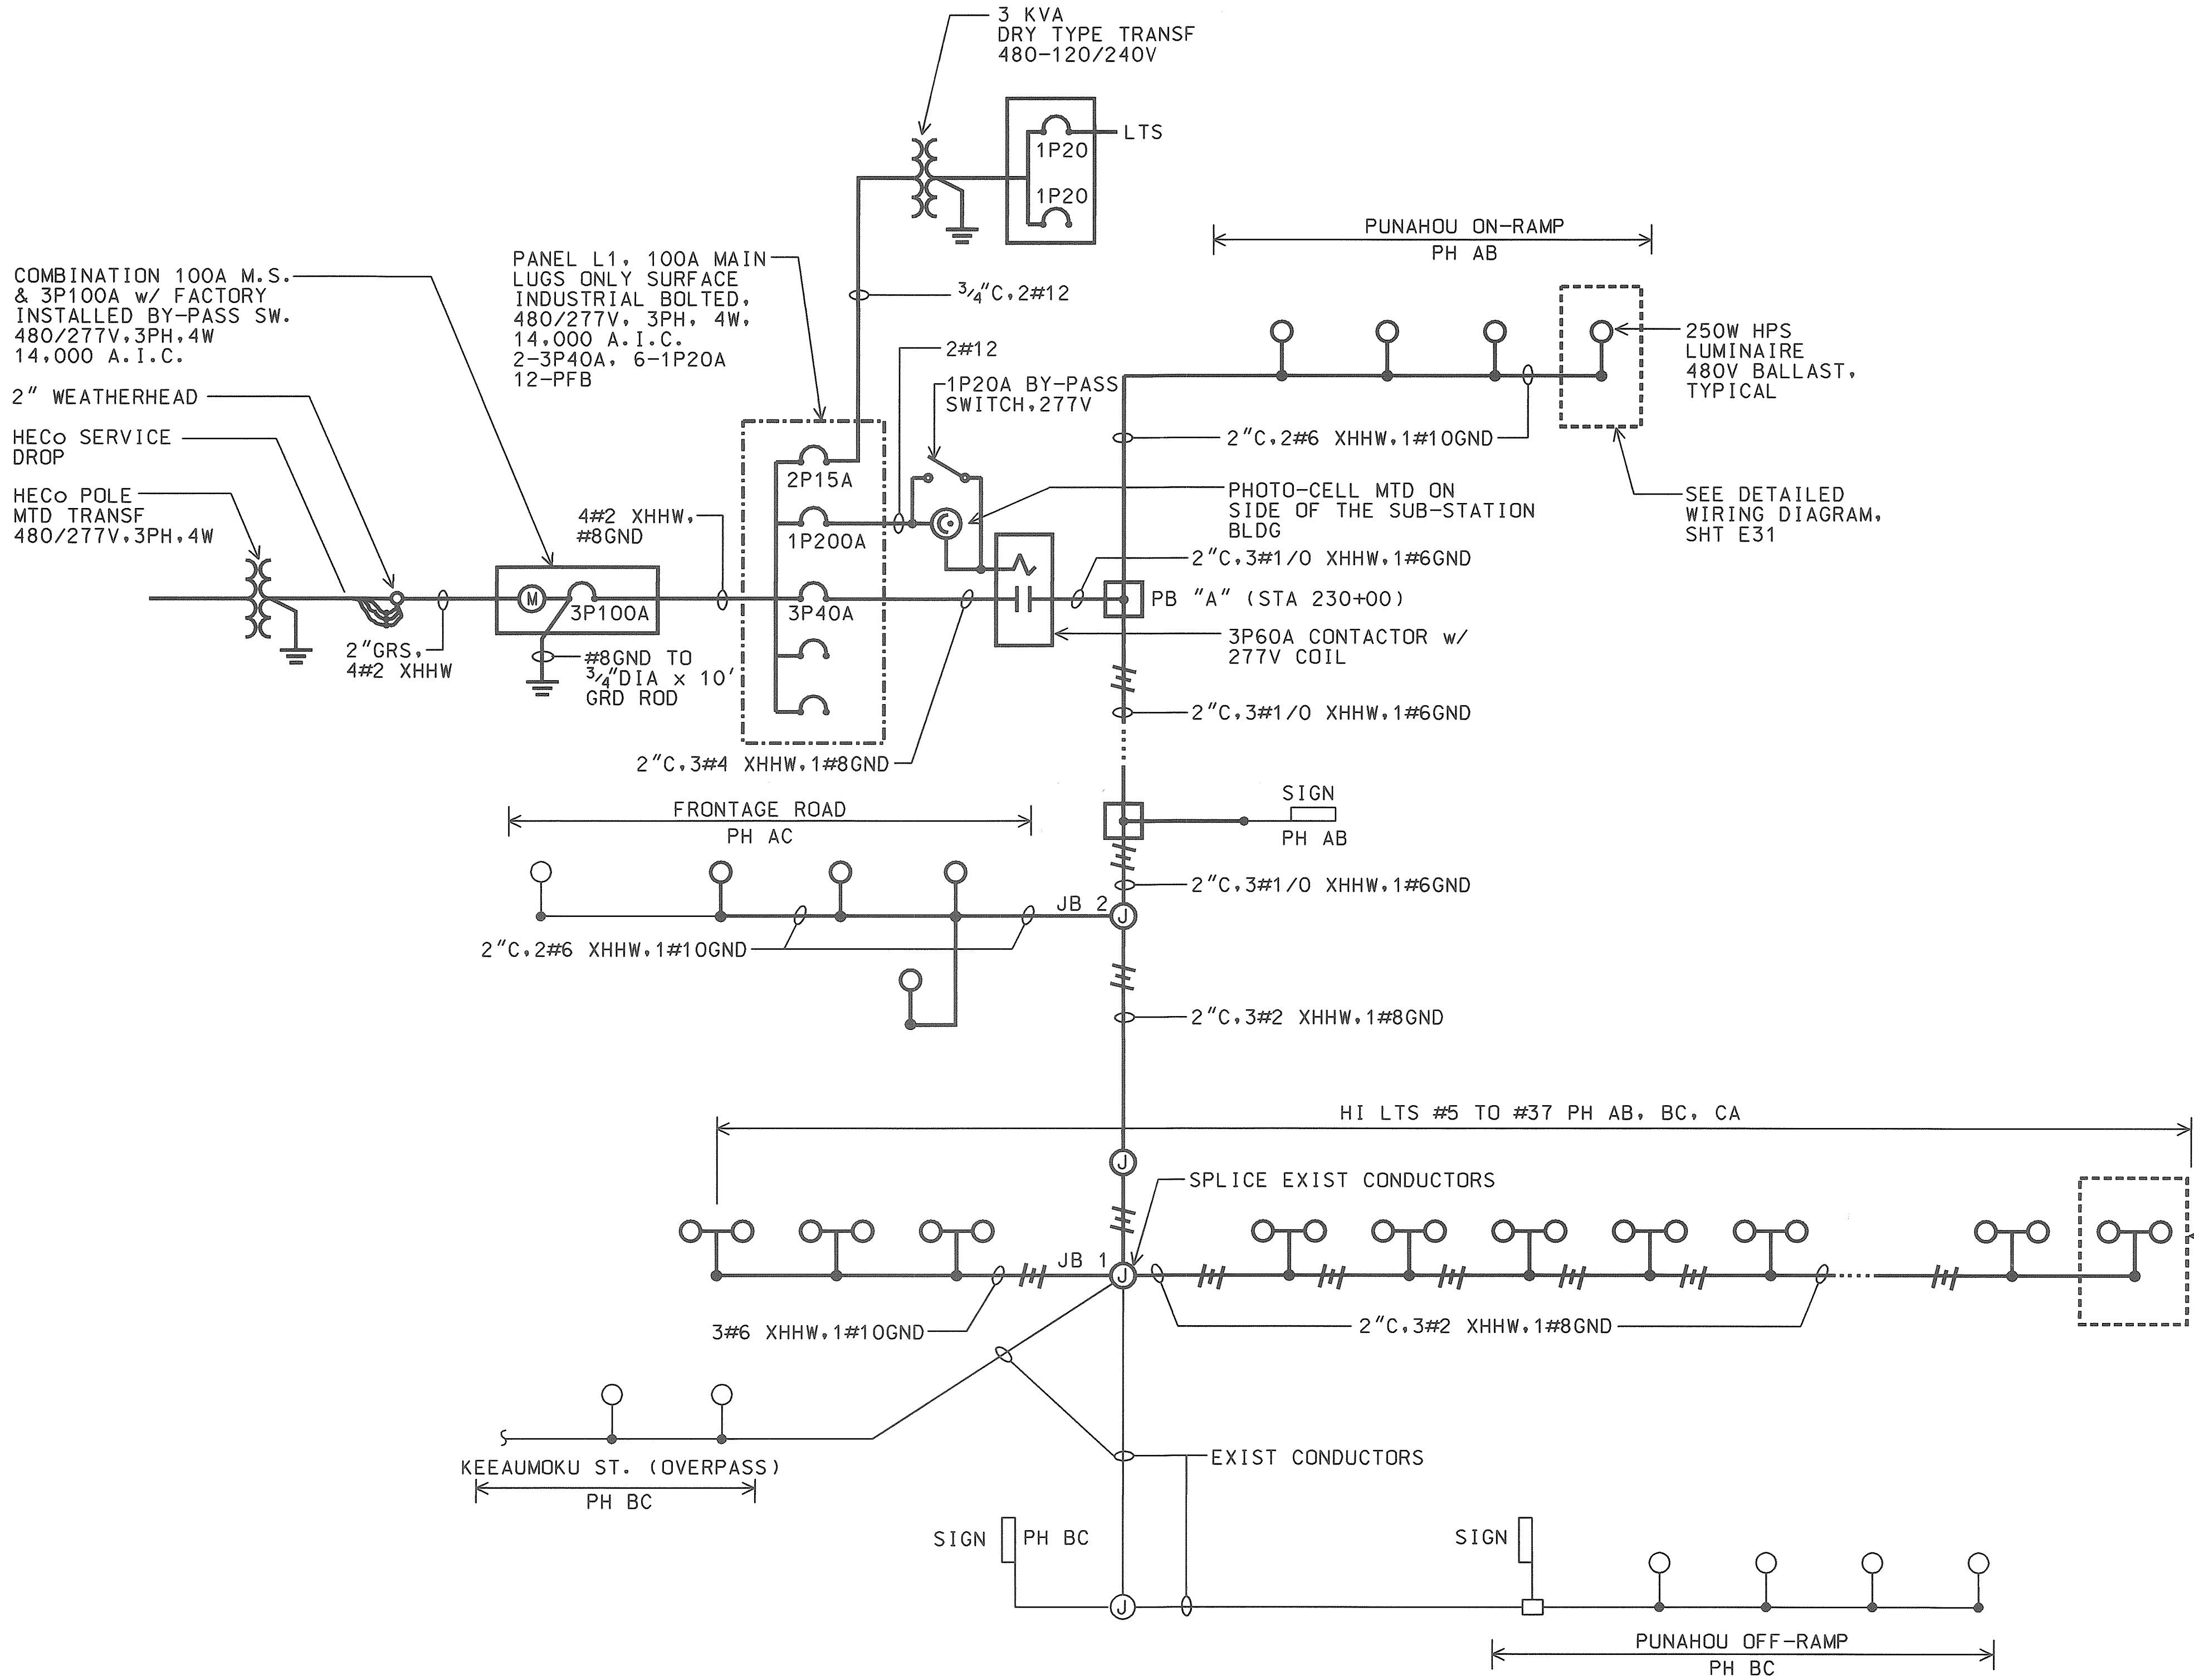

EXISTING ONE-LINE DIAGRAM: MAKIKI

98058-7L

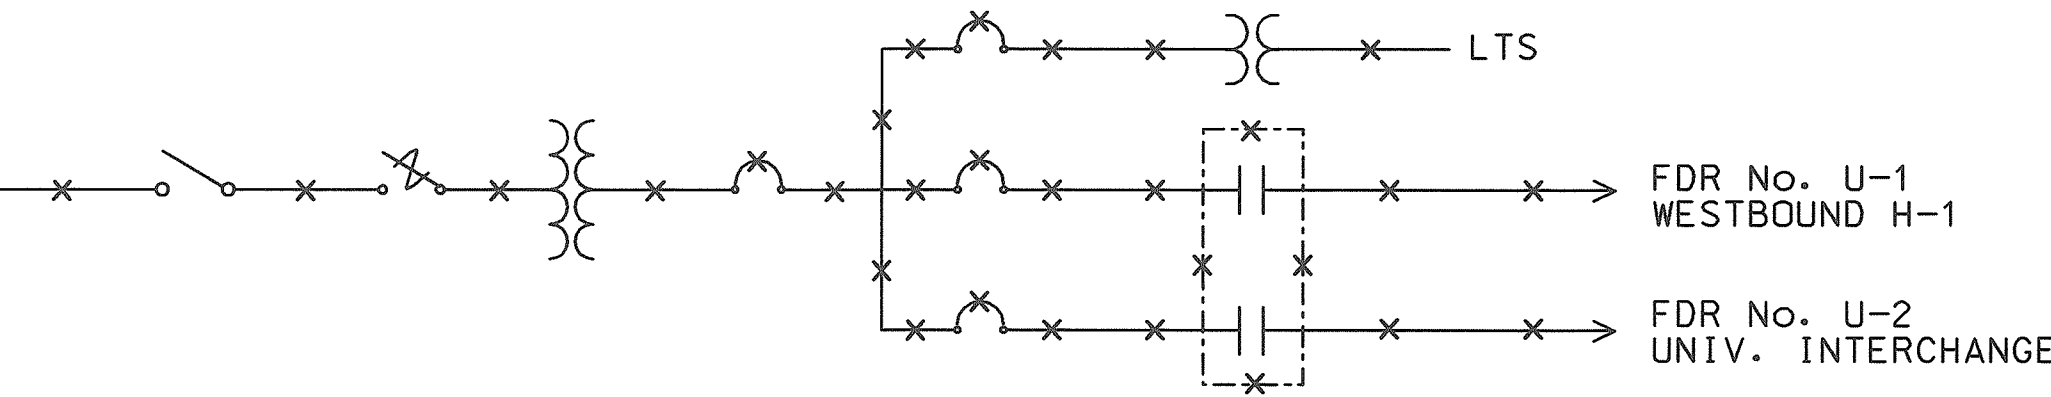

EXISTING ONE-LINE DIAGRAM: UNIVERSITY


98058-BL

ONE-LINE DIAGRAM - MAKIKI SUB-STATION

98058KDC

NOTES:

1. LIGHT LINES INDICATE EXISTING WORK.
BOLD LINES INDICATE NEW WORK.

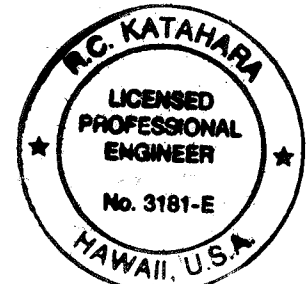


THIS WORK WAS PREPARED BY ME
OR UNDER MY SUPERVISION.
R.C. KATAHARA 1/25/98
MK ENGINEERS, LTD.

STATE OF HAWAII
DEPARTMENT OF TRANSPORTATION
HIGHWAYS DIVISION
**ONE-LINE DIAGRAM -
MAKIKI SUB-STATION**
HIGHWAY LIGHTING SAFETY IMPROVEMENTS
INTERSTATE ROUTE H-1
KEEAUMOKU STREET TO AINAKOA AVE

PROJECT NO. STP-0300(66)
SCALE: AS NOTED DATE: JANUARY 1999
SHEET No. E50 OF 56 SHEETS

AS-BUILT
2/9/99
DME

FED. ROAD DIST. NO.	STATE	FED. AID PROJ. NO.	FISCAL YEAR	SHEET NO.	TOTAL SHEETS
HAWAII	HAW.	STP-0300(66)	1998		

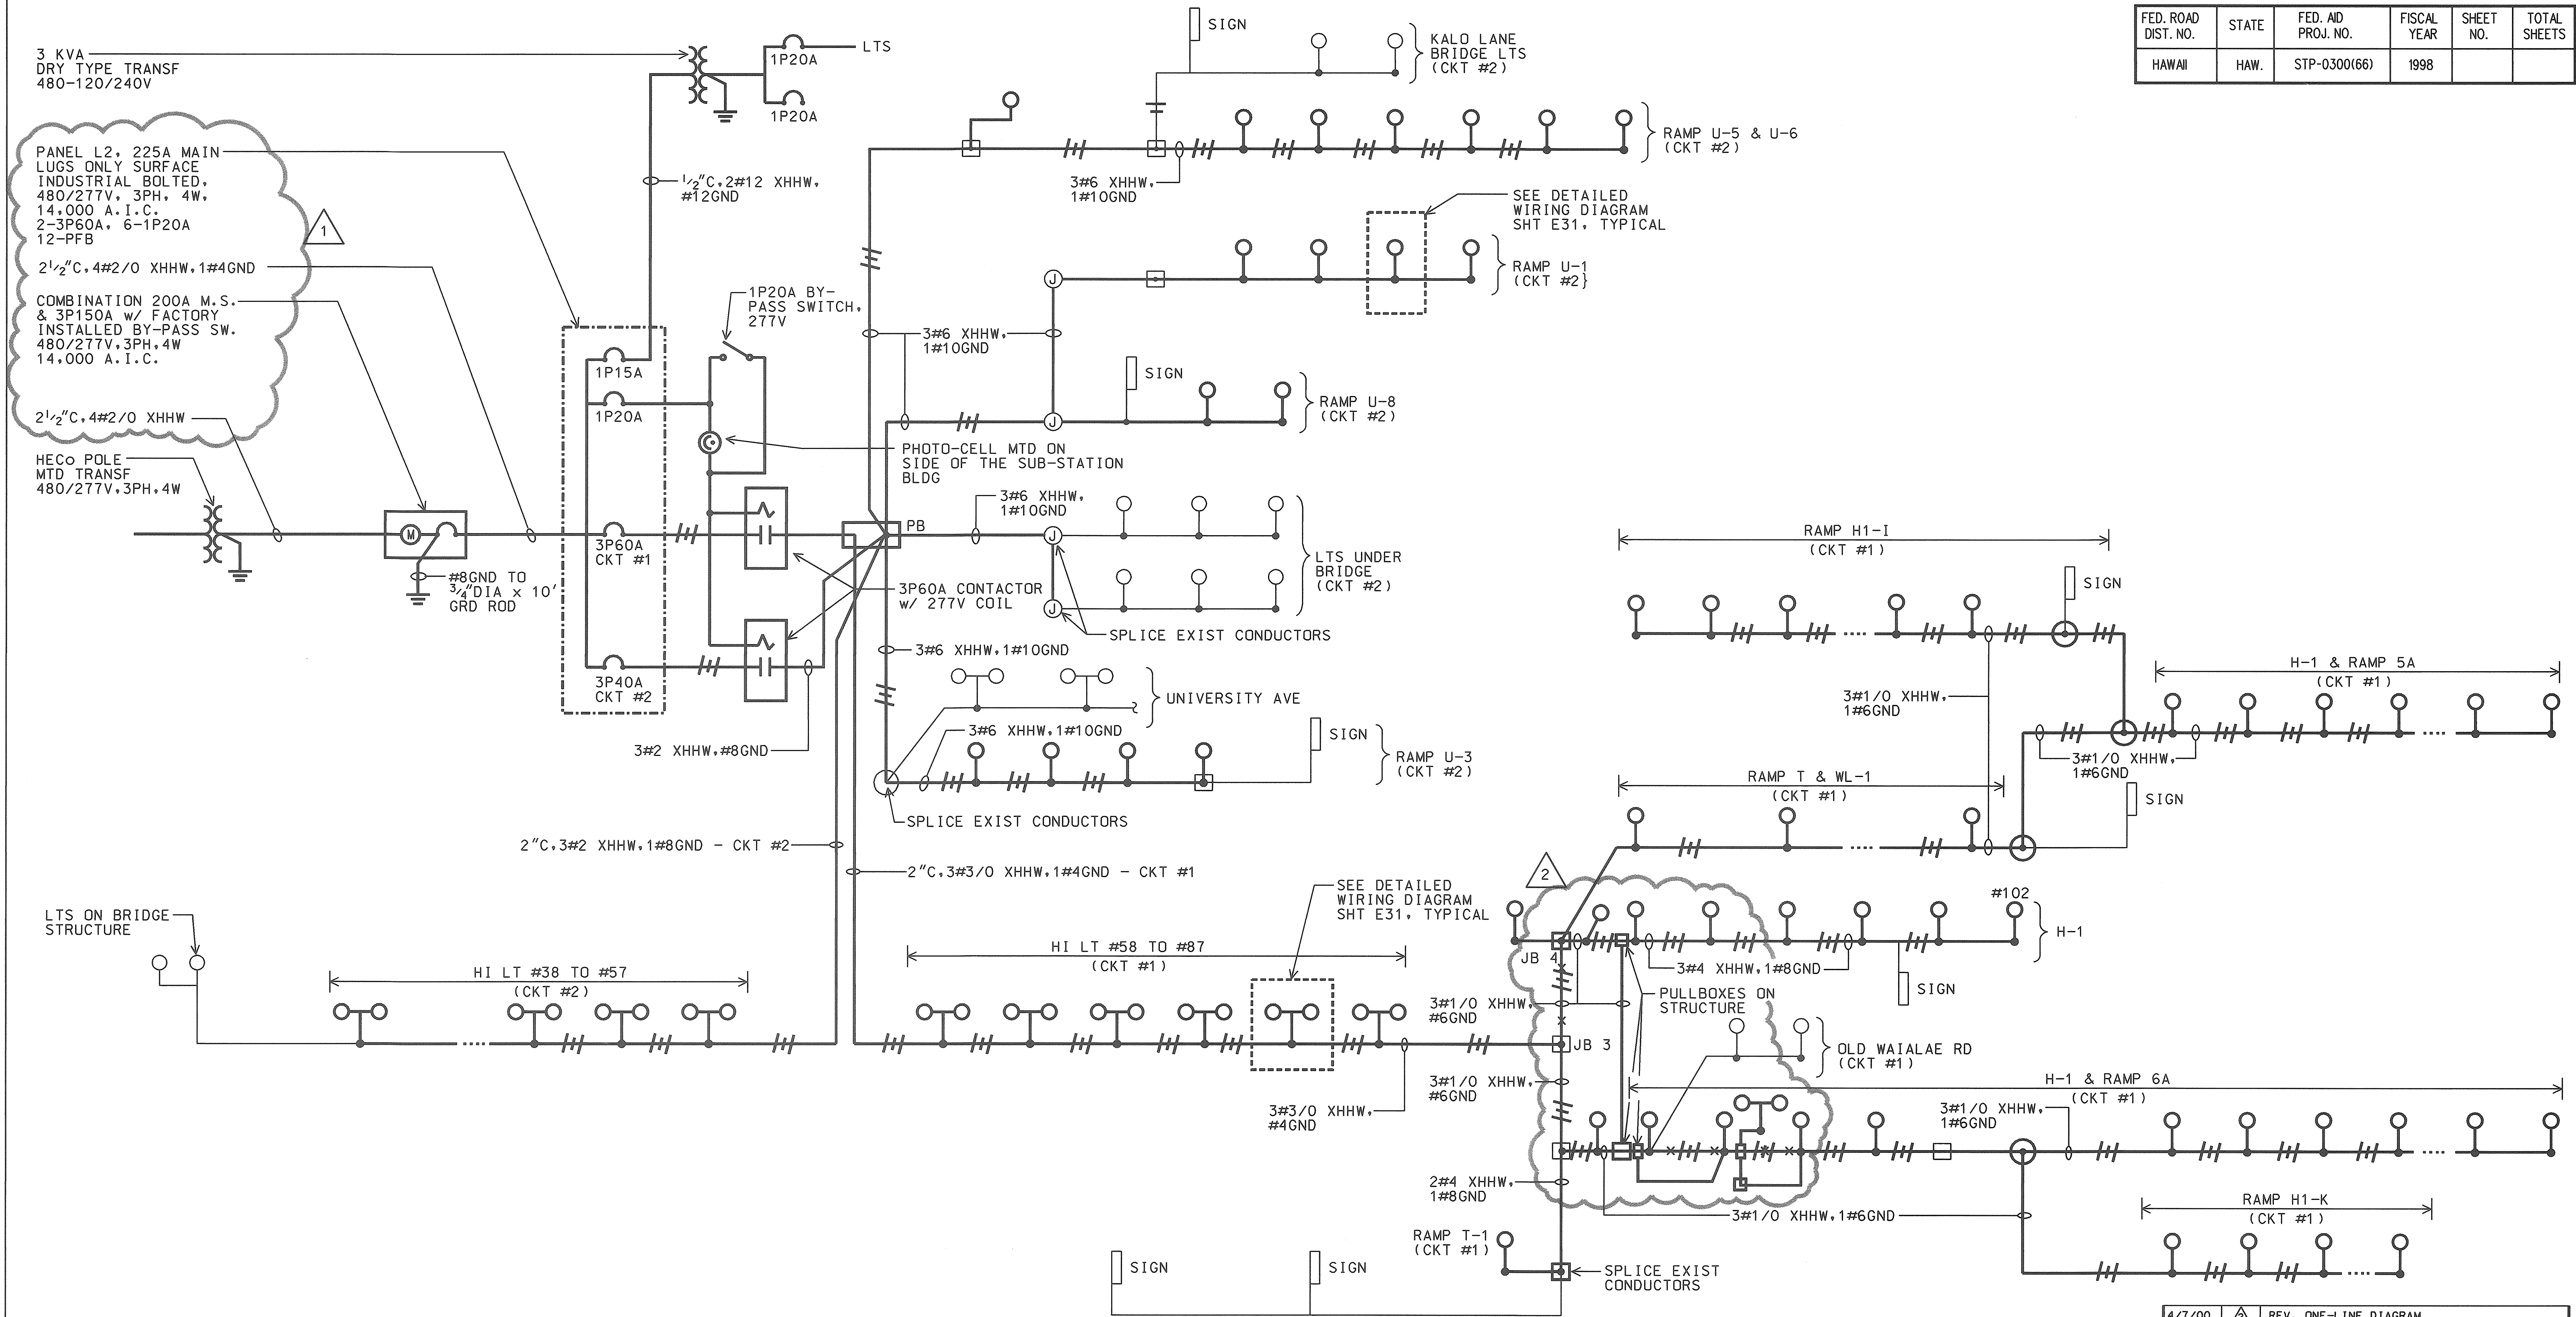


ONE-LINE DIAGRAM - UNIVERSITY SUB-STATION

NOTES:

1. ——— LIGHT LINES INDICATE EXISTING WORK.
——— BOLD LINES INDICATE NEW WORK.

AS-BUILT
2/4/03
DATE

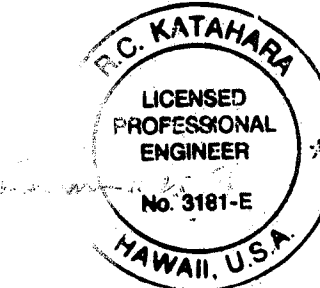


THIS WORK WAS PREPARED BY ME
OR UNDER MY SUPERVISION.
R.C. KATAHARA 2/25/98
MK ENGINEERS, LTD.

DATE	REV	DESCRIPTION
4/7/00	Δ	REV. ONE-LINE DIAGRAM
8/16/99	Δ	REV. ONE-LINE DIAGRAM
STATE OF HAWAII DEPARTMENT OF TRANSPORTATION HIGHWAYS DIVISION ONE-LINE DIAGRAM - UNIVERSITY SUB-STATION HIGHWAY LIGHTING SAFETY IMPROVEMENTS INTERSTATE ROUTE H-1 KEEAUMOKU STREET TO AINAKOA AVE PROJECT NO. STP-0300(66) SCALE: AS NOTED DATE: JANUARY 1999 SHEET No. E51 OF 56 SHEETS		


C0-E51

FED. ROAD DIST. NO.	STATE	FED. AID PROJ. NO.	FISCAL YEAR	SHEET NO.	TOTAL SHEETS
HAWAII	HAW.	STP-0300(66)	1998		

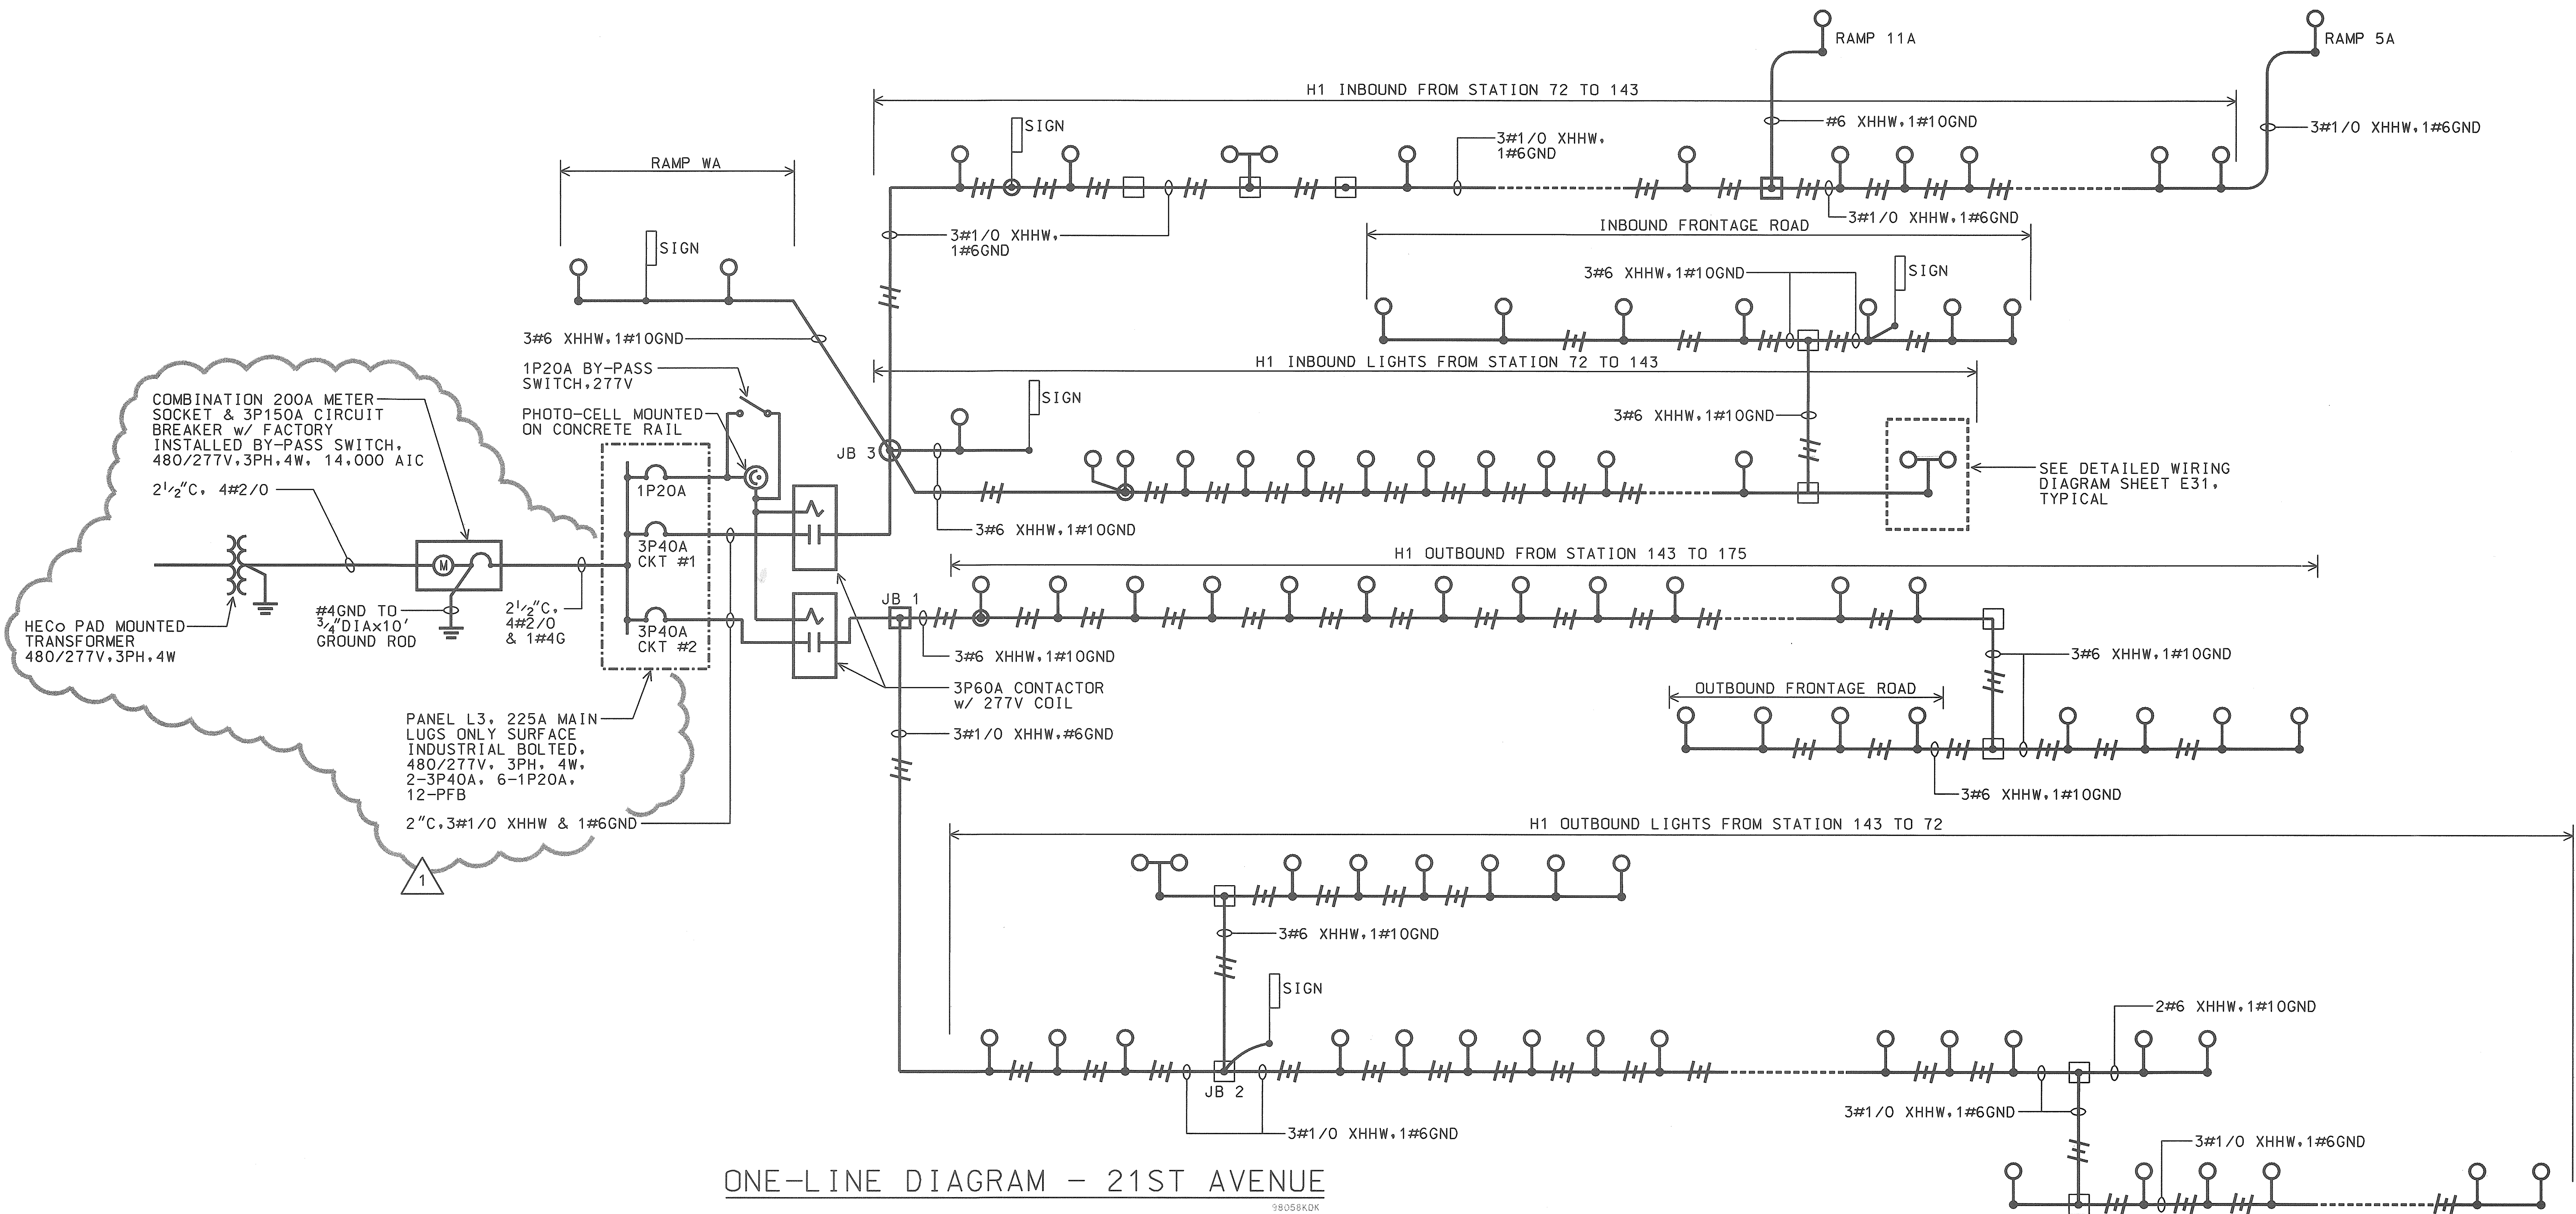

ONE-LINE DIAGRAM - 21ST AVENUE

- NOTES:
1. ——— LIGHT LINES INDICATE EXISTING WORK.
———— BOLD LINES INDICATE NEW WORK.



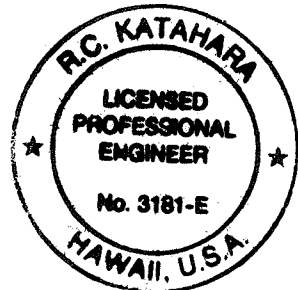


AS-BUILT
2/4/03
DATE




THIS WORK WAS PREPARED BY ME
OR UNDER MY SUPERVISION.
R.C. KATAHARA 11/25/98
MK ENGINEERS, LTD.

DATE	REV	DESCRIPTION
8/16/99	1	REV. ONE - LINE DIAGRAM
STATE OF HAWAII DEPARTMENT OF TRANSPORTATION HIGHWAYS DIVISION ONE-LINE DIAGRAM - 21ST AVENUE HIGHWAY LIGHTING SAFETY IMPROVEMENTS INTERSTATE ROUTE H-1 KEEAUWOKU STREET TO AINAKOA AVE PROJECT NO. STP-0300(66) SCALE: AS NOTED DATE: JANUARY 1999 SHEET No. E52 OF 56 SHEETS		

FED. ROAD DIST. NO.	STATE	FED. AID PROJ. NO.	FISCAL YEAR	SHEET NO.	TOTAL SHEETS
HAWAII	HAW.	STP-0300(66)	1998		

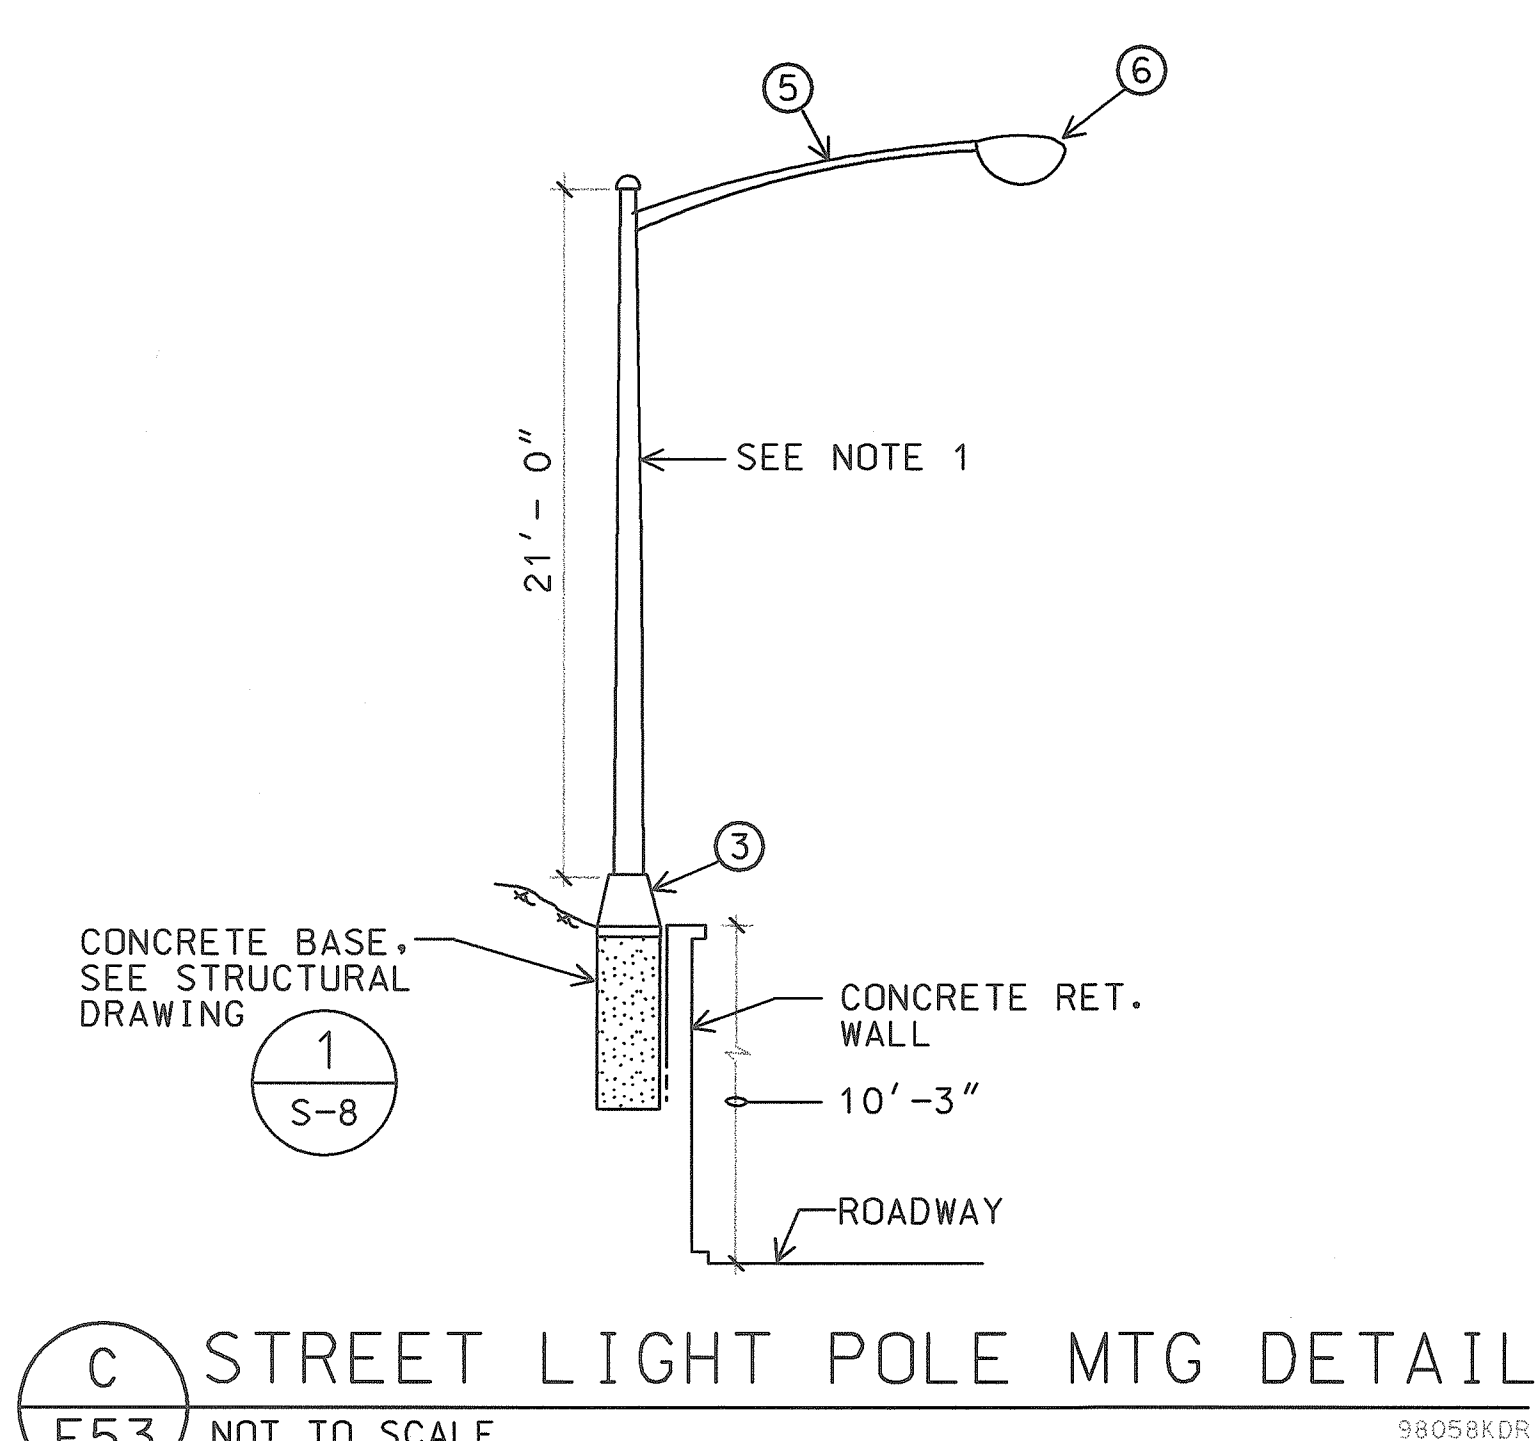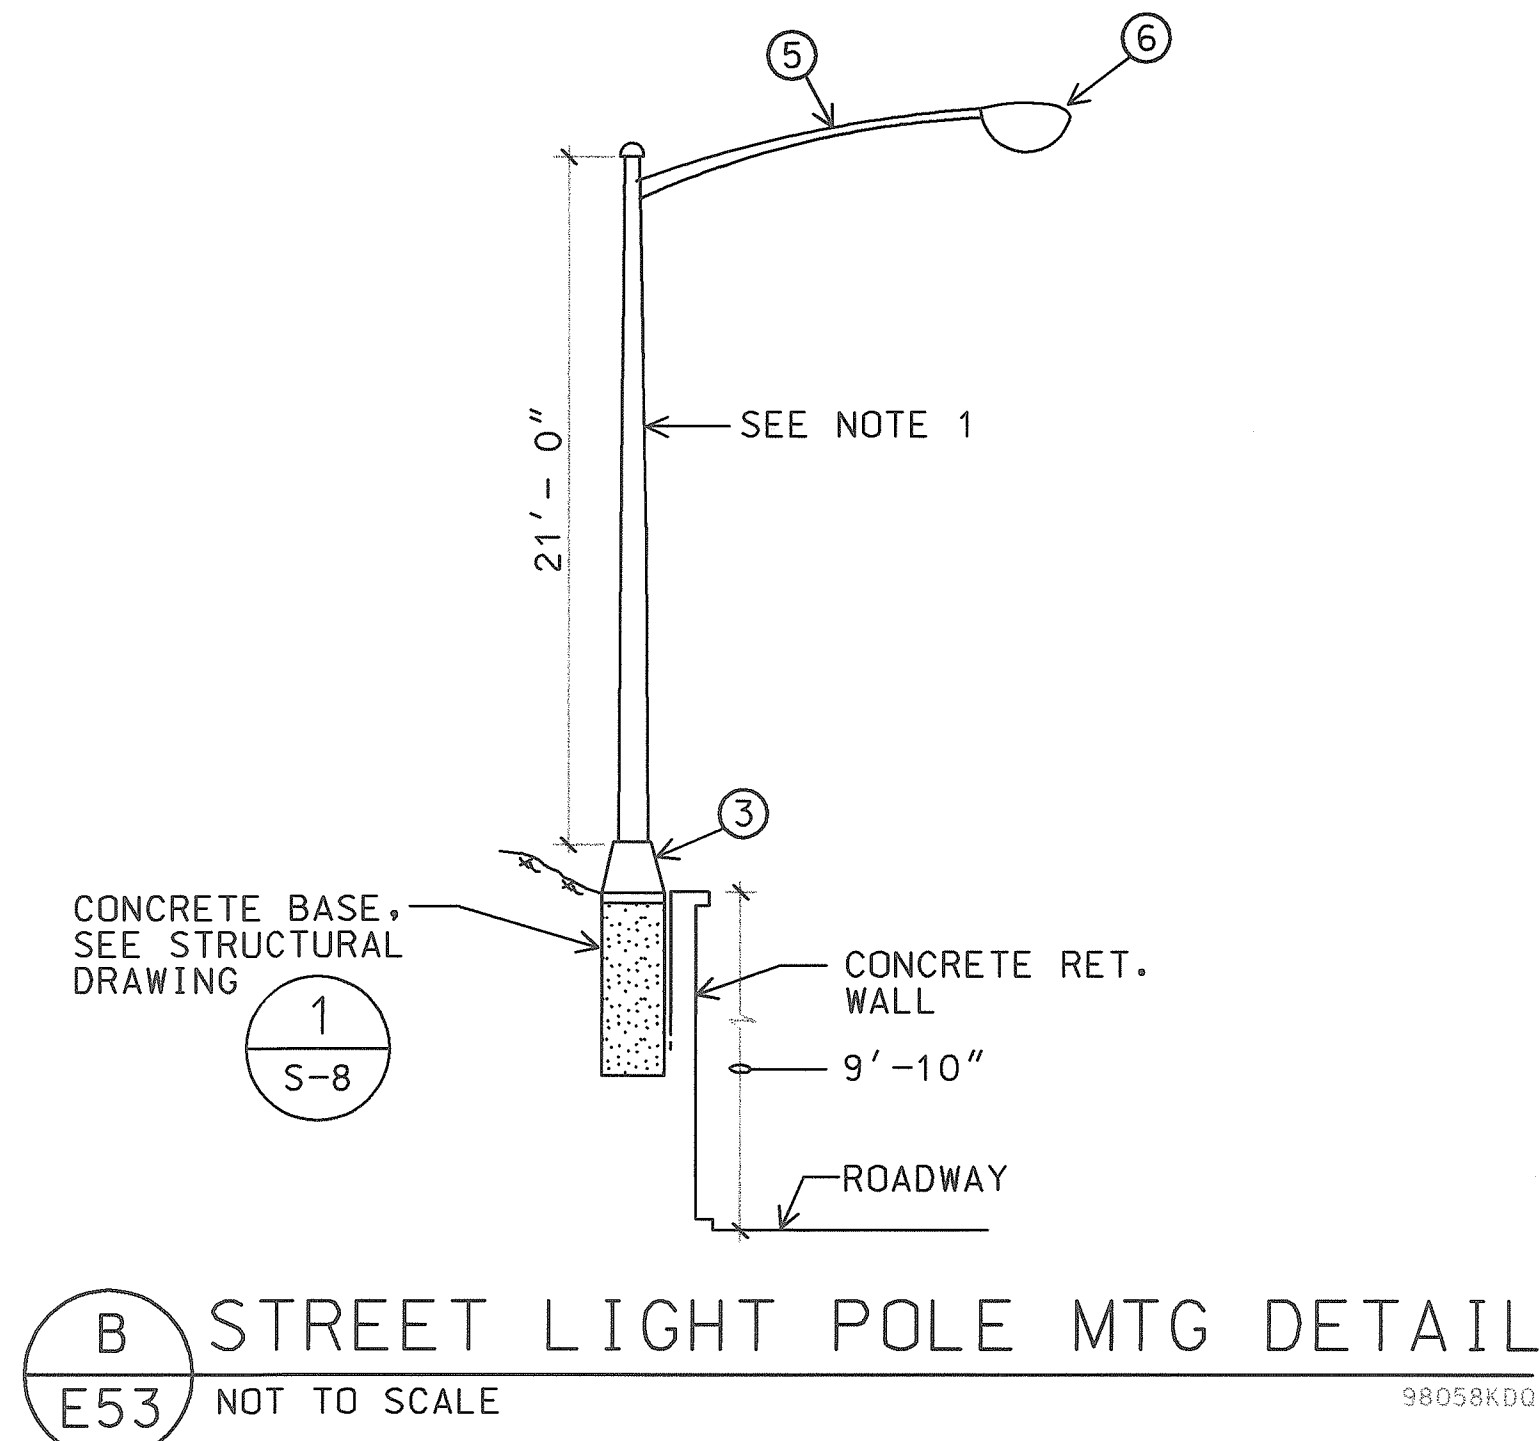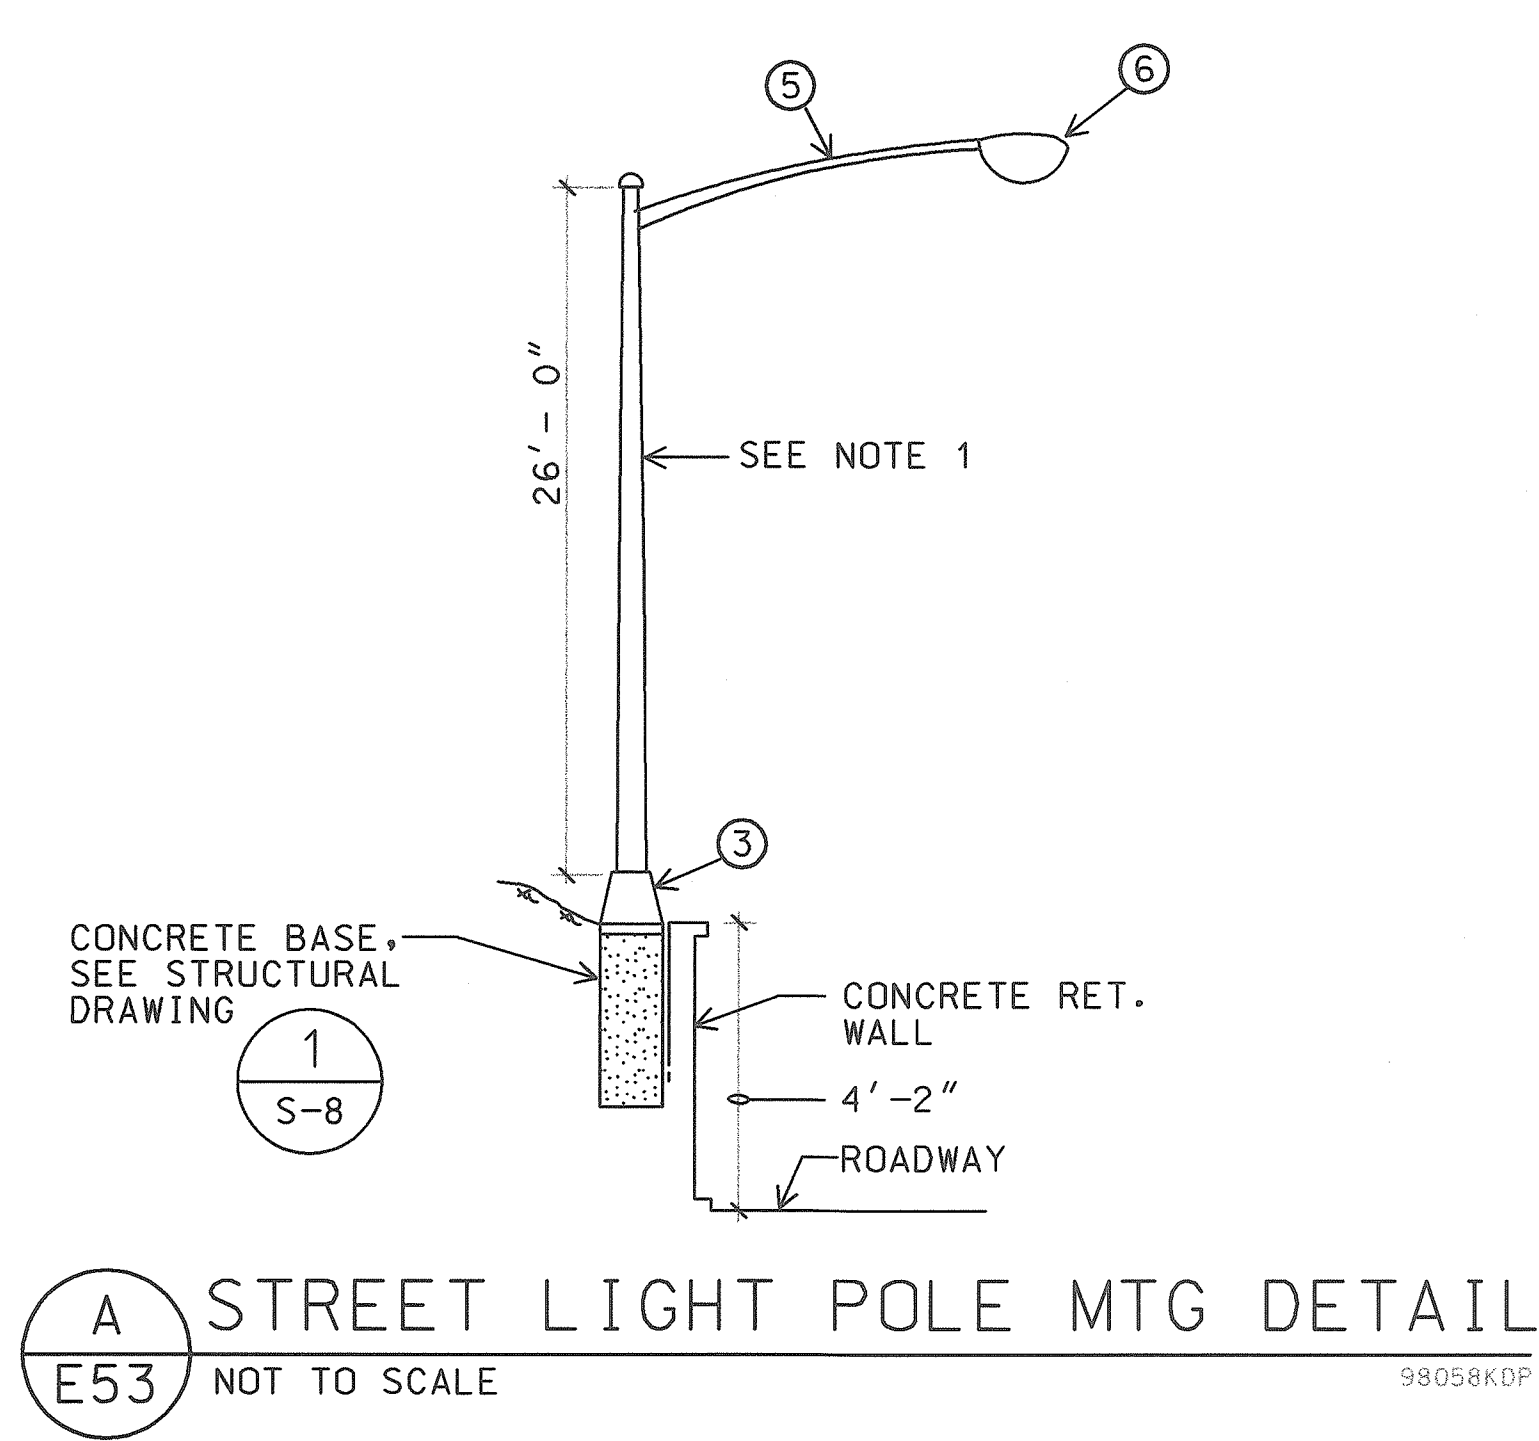

- NOTES:**
1. SATIN BRUSHED FINISH ALUMINUM POLE WITH INTERNALLY MOUNTED FACTORY INSTALLED VIBRATION DAMPER. MUST WITHSTAND 100 MPH WIND VELOCITY WITH 1.3 GUST FACTOR PER AASHTO & BE FREE FROM WHITE RUST.

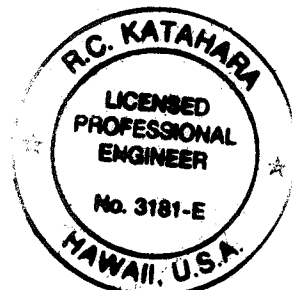
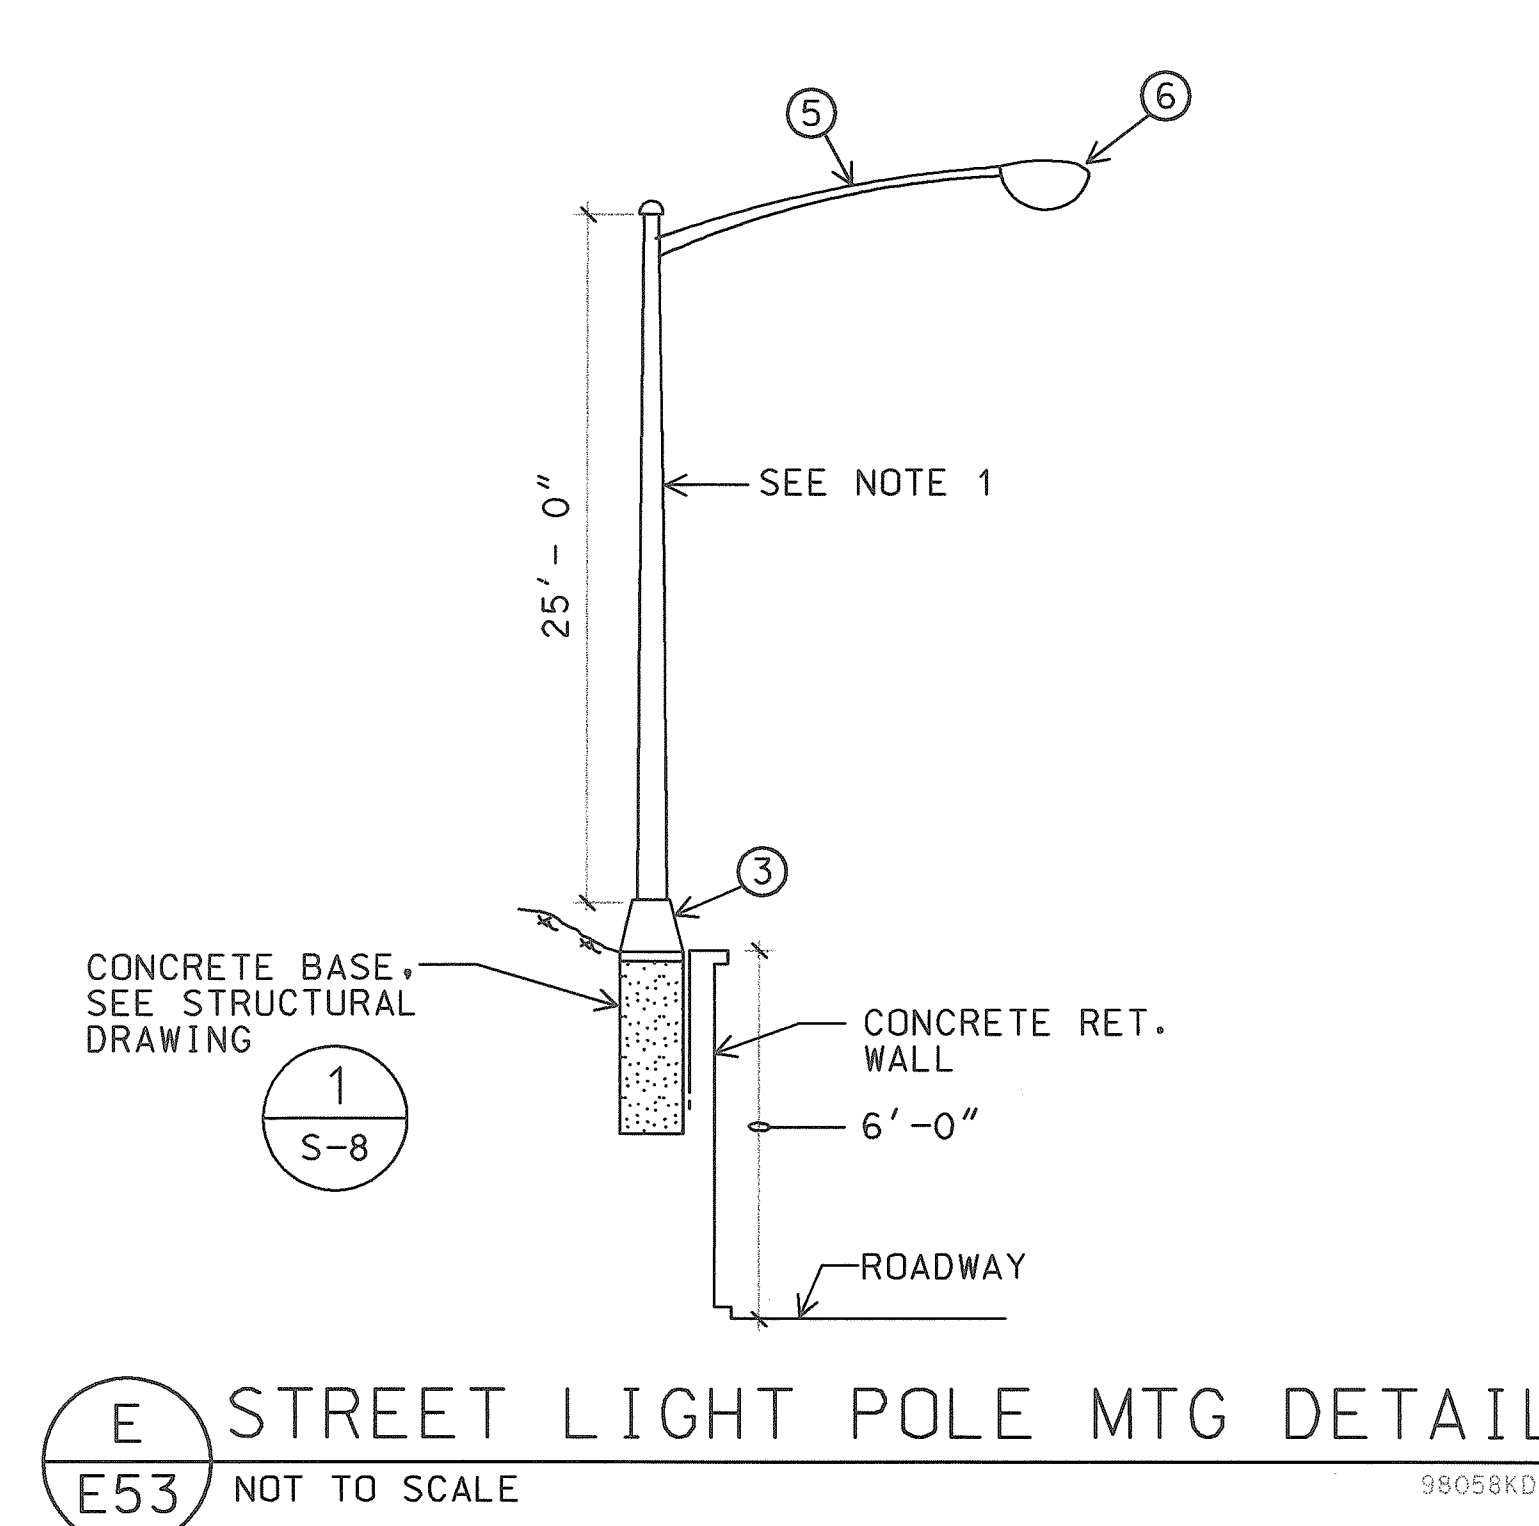
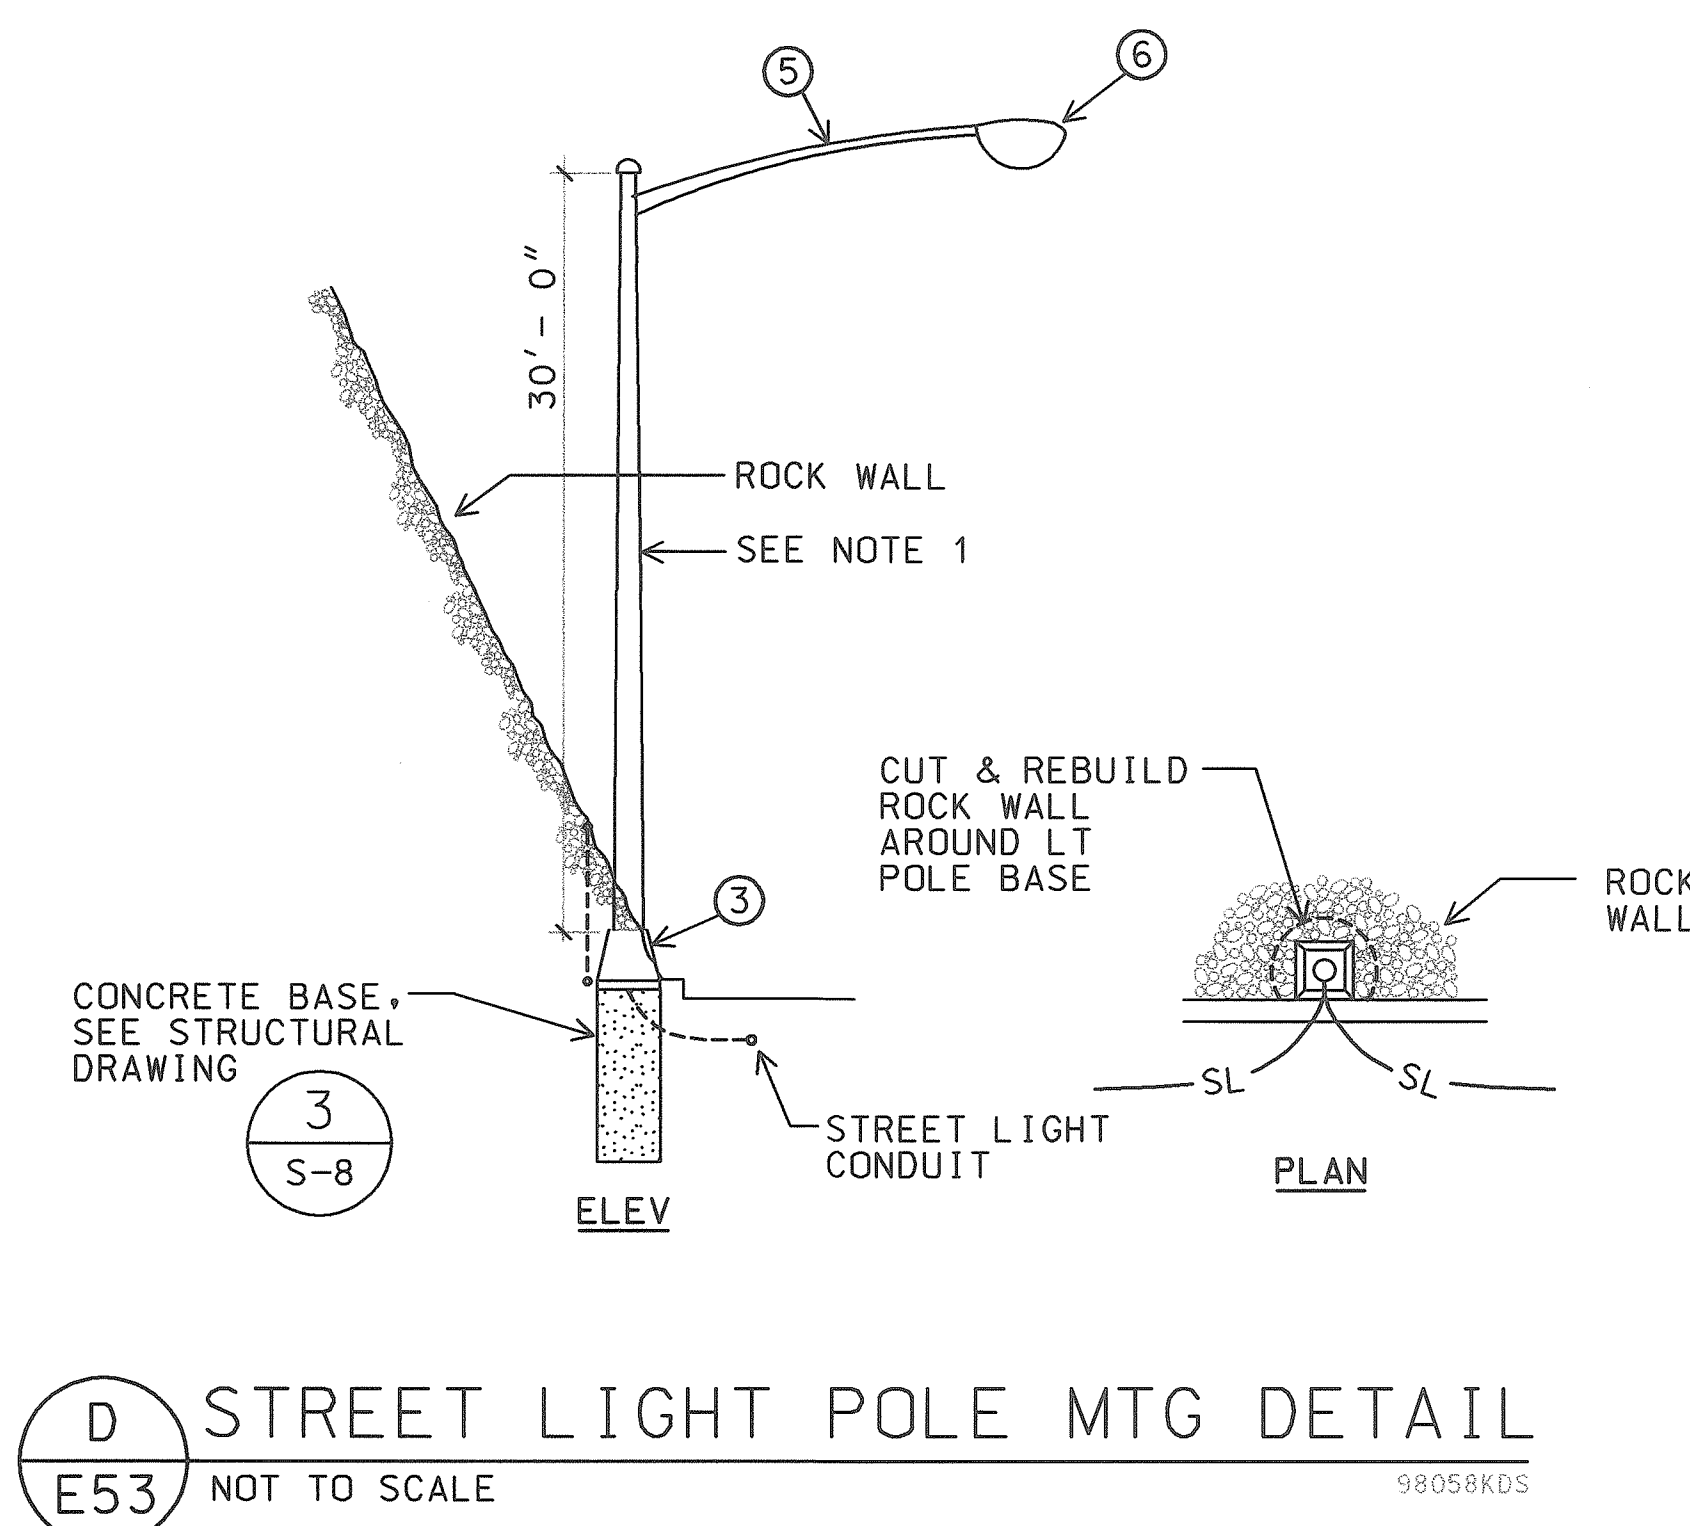


AS-BUILT
2/4/03
DATE




THIS WORK WAS PREPARED BY ME
OR UNDER MY SUPERVISION.
R.C. KATAHARA 2/25/03
MK ENGINEERS, LTD.

STATE OF HAWAII
DEPARTMENT OF TRANSPORTATION
HIGHWAYS DIVISION
STREET LIGHT POLE DETAILS
HIGHWAY LIGHTING SAFETY IMPROVEMENTS
INTERSTATE ROUTE H-1
KEEAUMOKU STREET TO AINAKOA AVE
PROJECT NO. STP-0300(66)
SCALE: AS NOTED DATE: JANUARY 1999
SHEET No. E53 OF 56 SHEETS

FED. ROAD DIST. NO.	STATE	FED. AID PROJ. NO.	FISCAL YEAR	SHEET NO.	TOTAL SHEETS
HAWAII	HAW.	STP-0300(66)	1998		

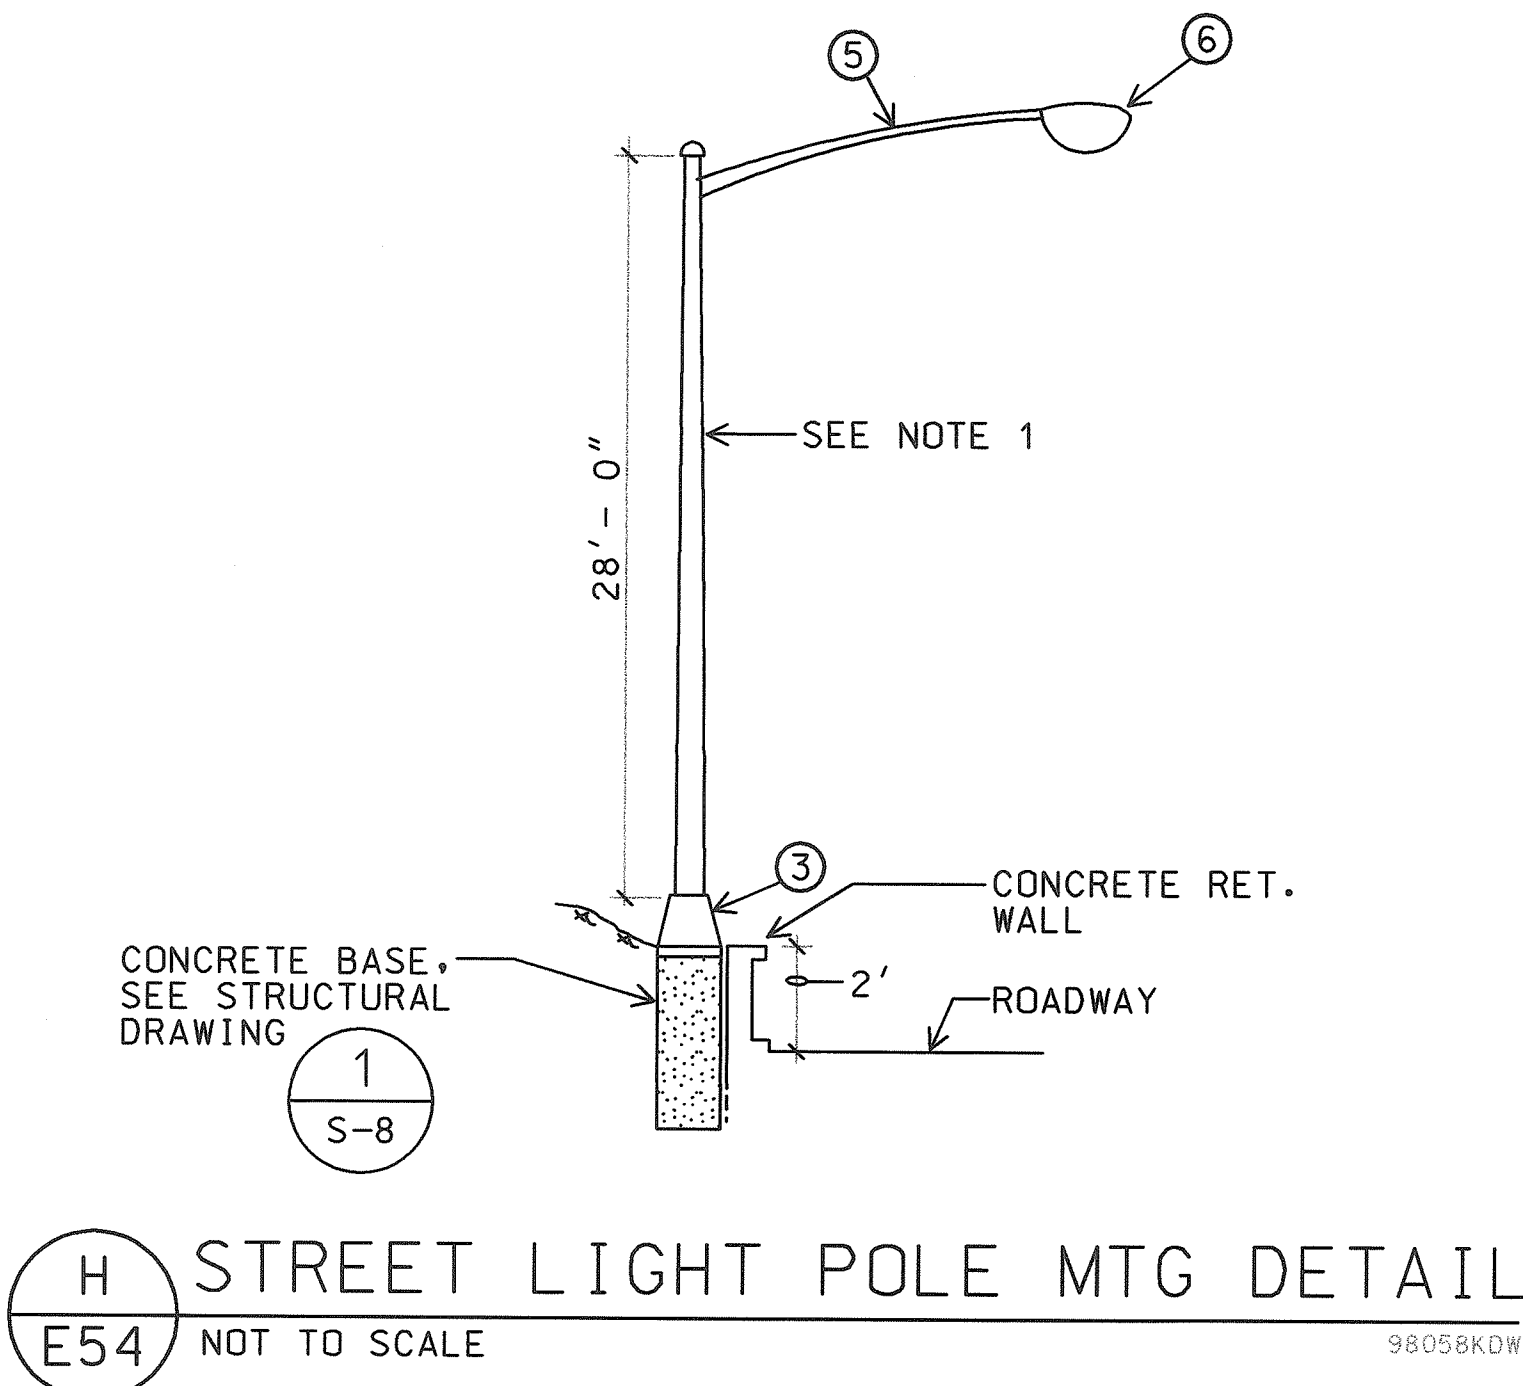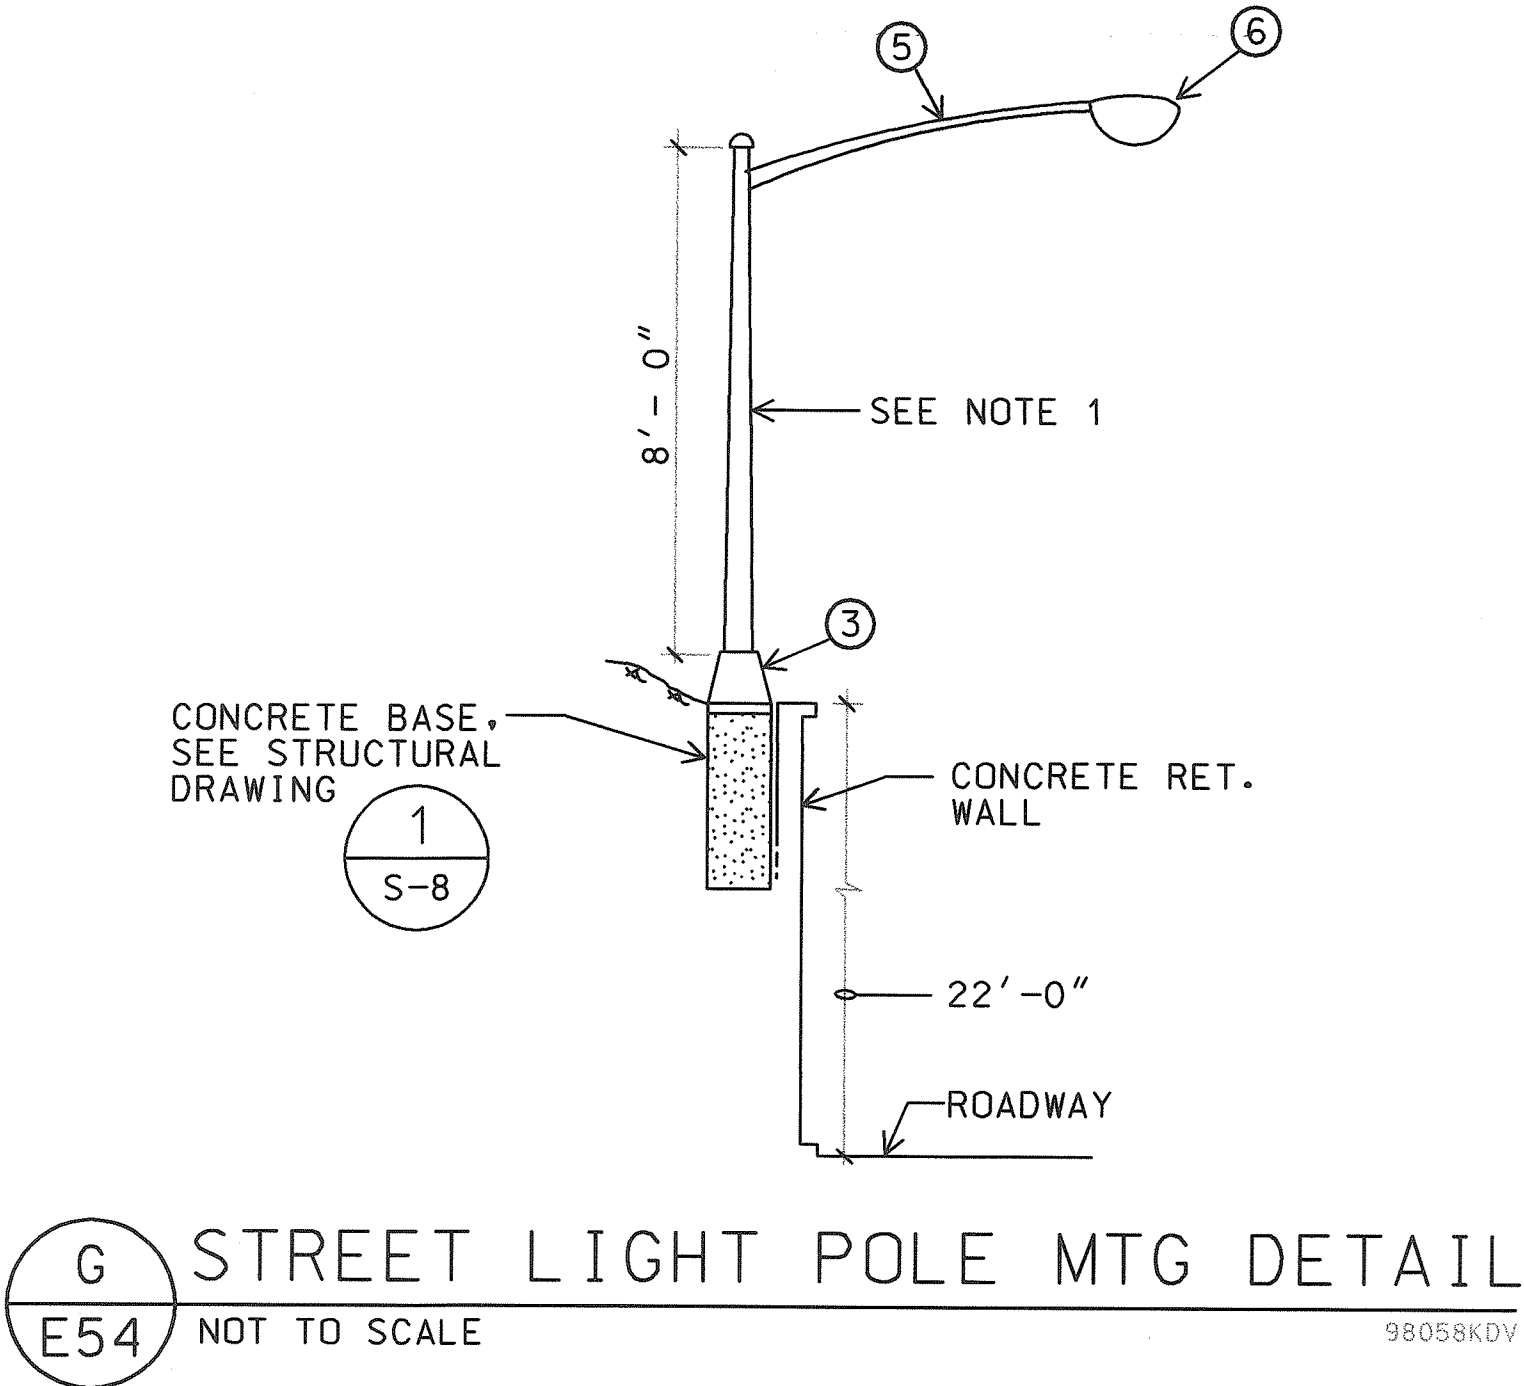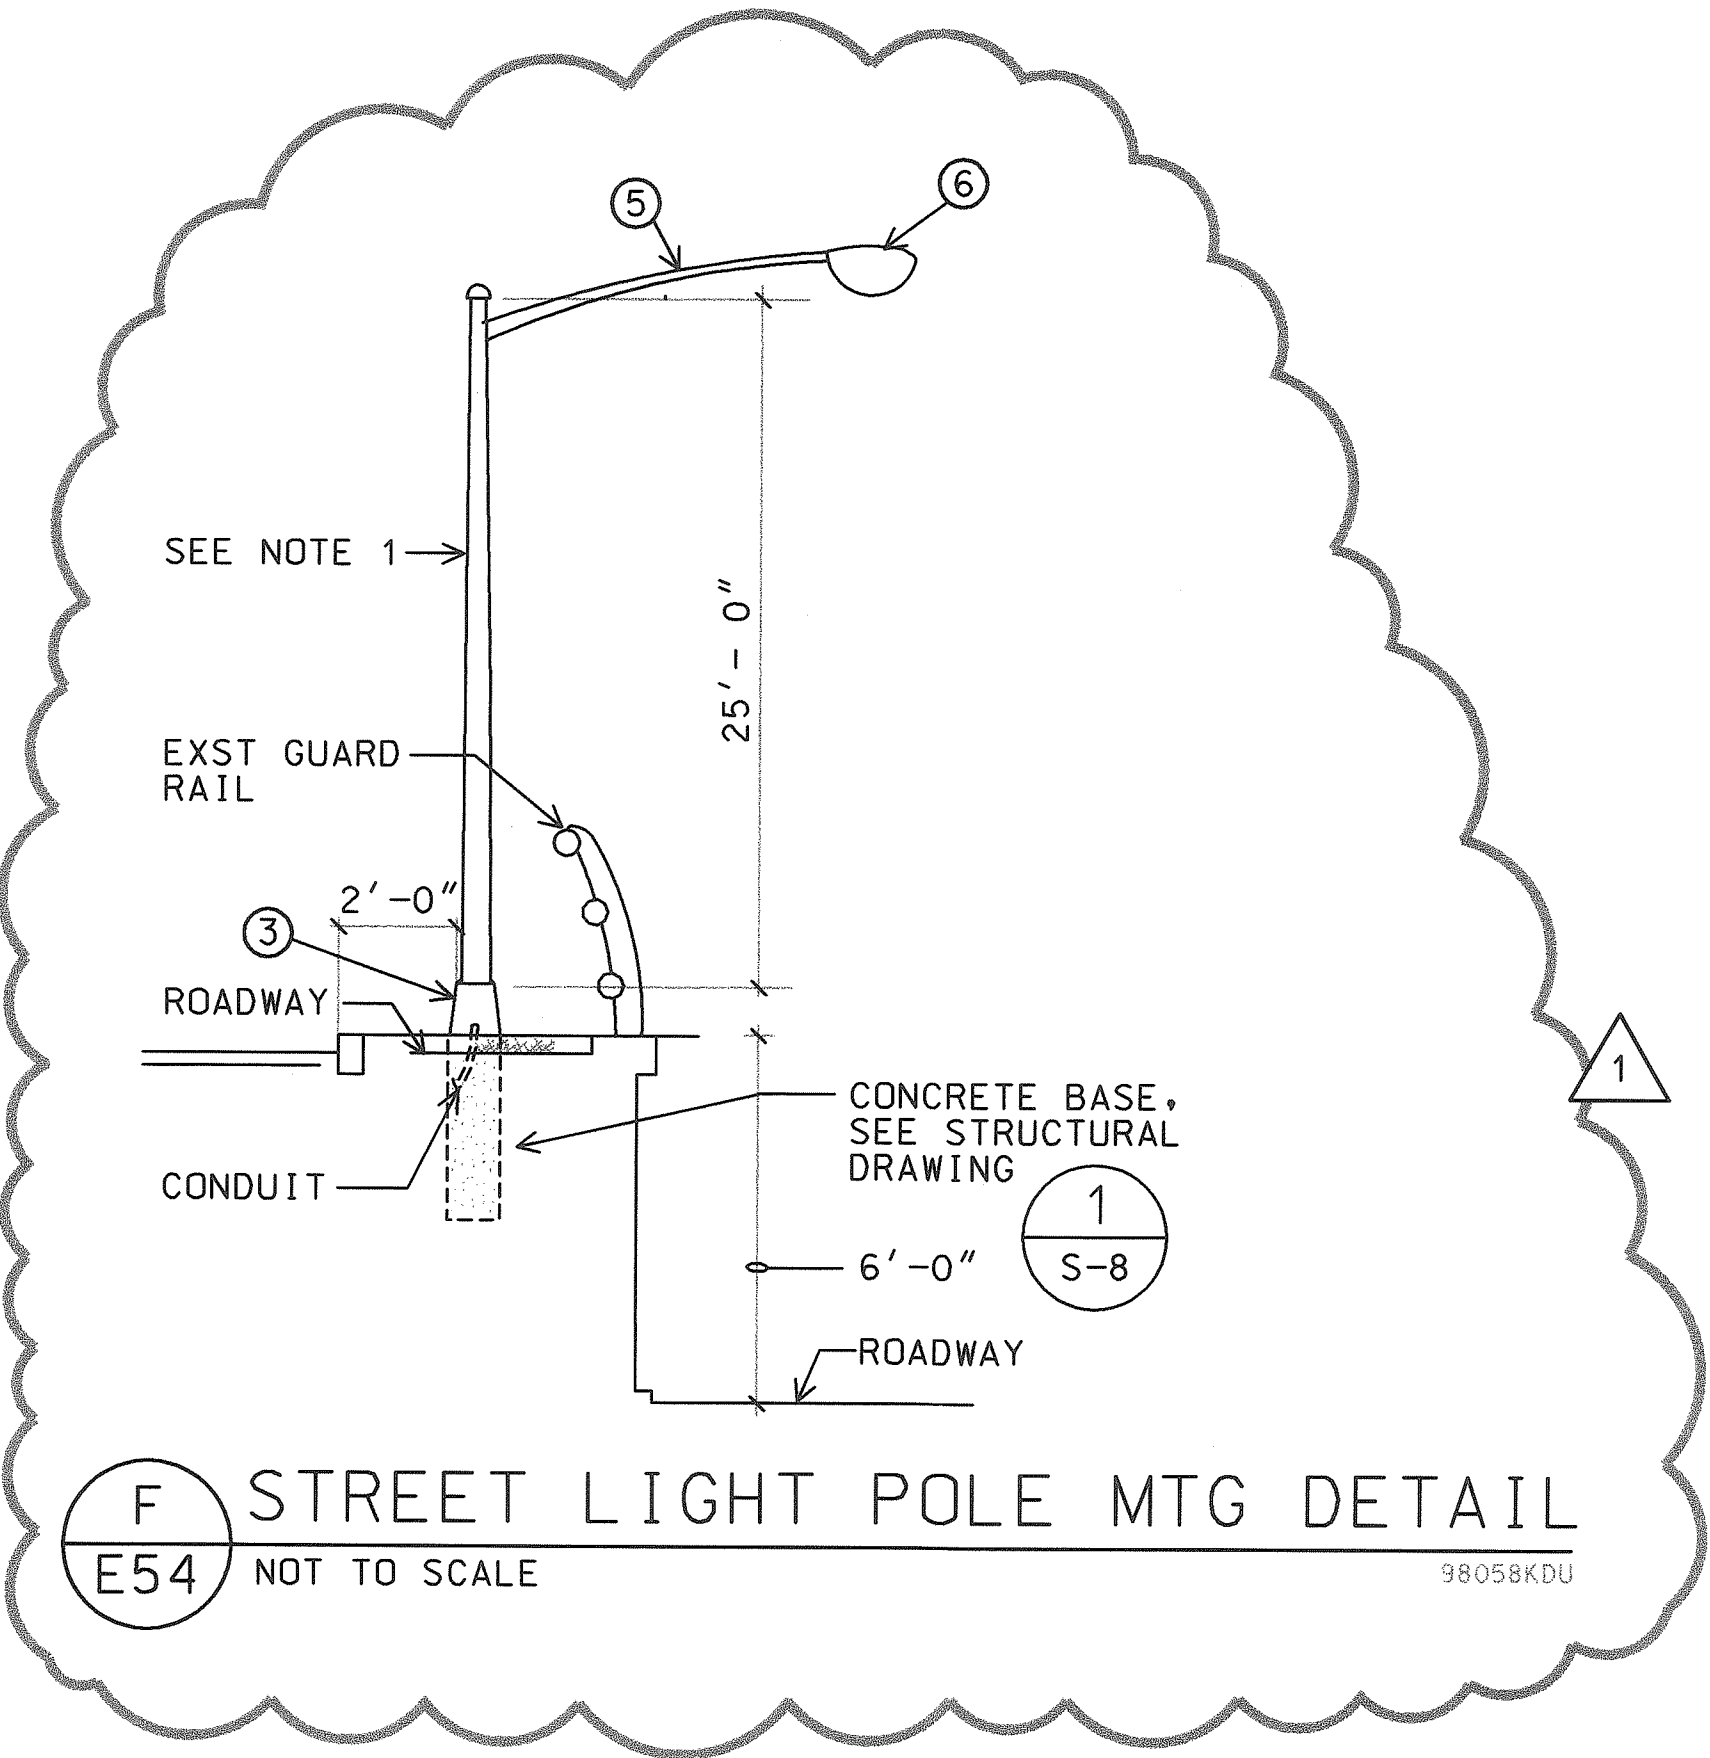

- NOTES:**
1. SATIN BRUSHED FINISH ALUMINUM POLE WITH INTERNALLY MOUNTED FACTORY INSTALLED VIBRATION DAMPER. MUST WITHSTAND 100 MPH WIND VELOCITY WITH 1.3 GUST FACTOR PER AASHTO & BE FREE FROM WHITE RUST.




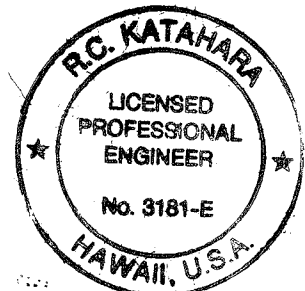
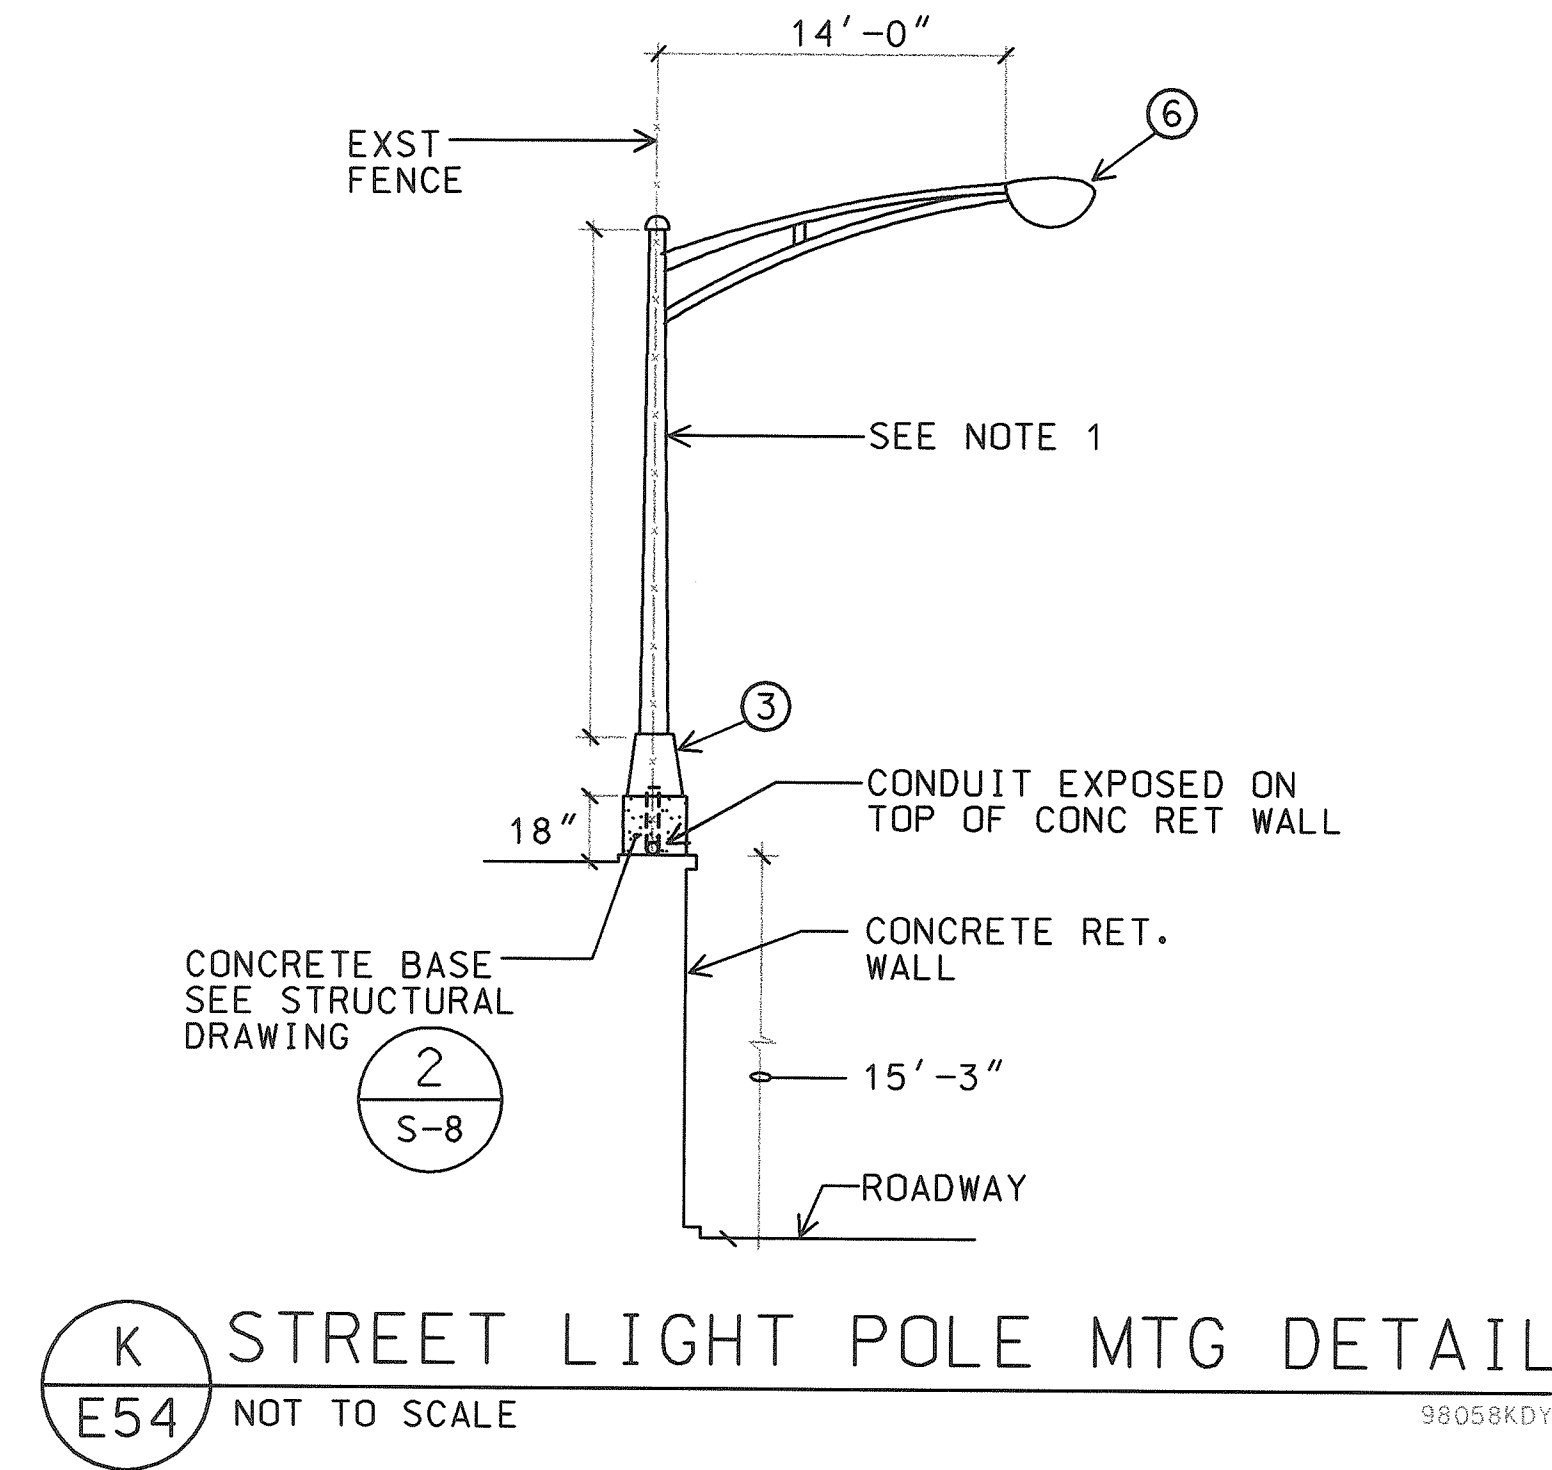
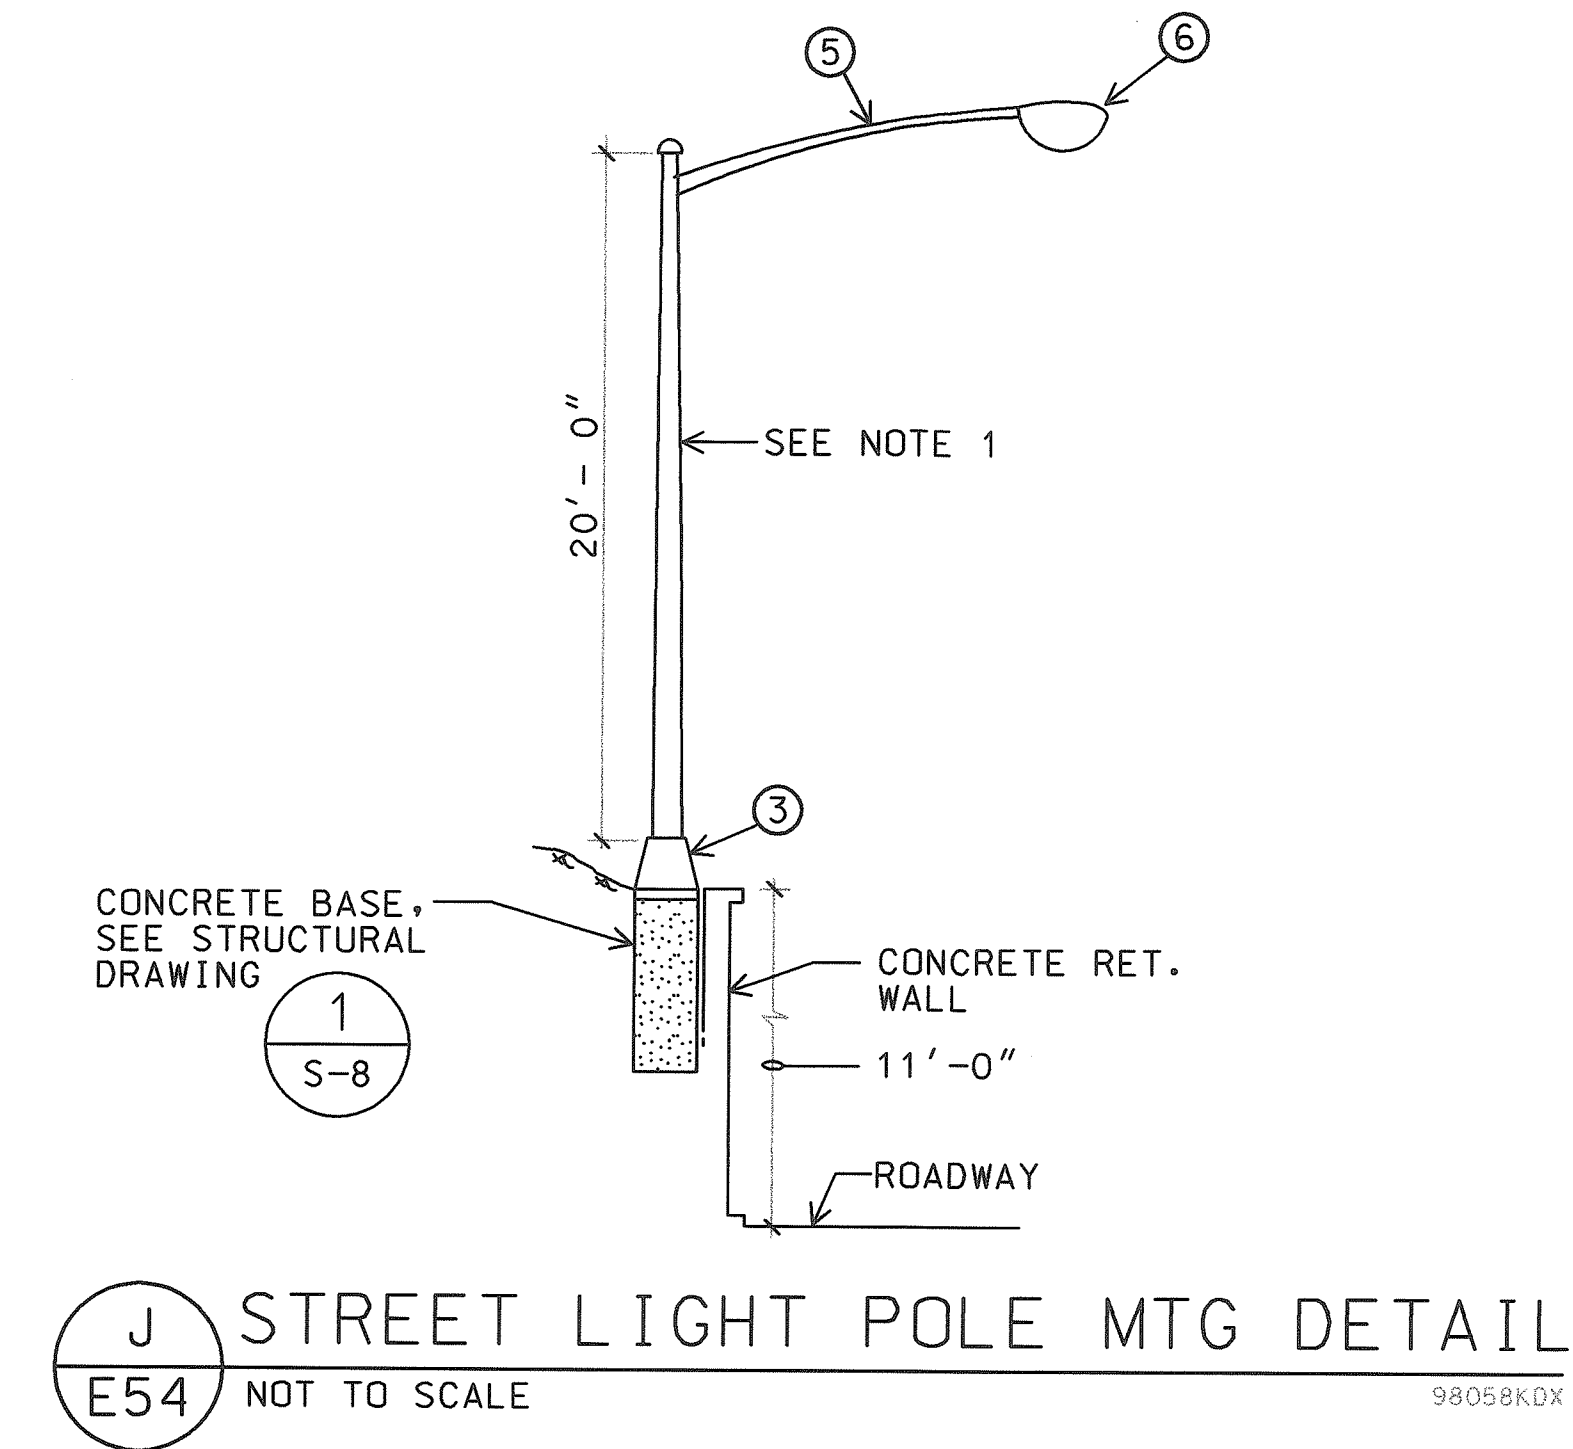


THIS WORK WAS PREPARED BY ME
OR UNDER MY SUPERVISION
R.C. KATAHARA 5/24/04
RK ENGINEERS, LTD.

12/17/99		REV. LOCATION OF LT POLE	
DATE	REV	DESCRIPTION	
STATE OF HAWAII DEPARTMENT OF TRANSPORTATION HIGHWAYS DIVISION			
<u>STREET LIGHT POLE DETAILS</u>			
<u>HIGHWAY LIGHTING SAFETY IMPROVEMENTS</u> <u>INTERSTATE ROUTE H-1</u> <u>KEEAUMOKU STREET TO AINAKOA AVE</u>			
<u>PROJECT NO. STP-0300(66)</u>			
SCALE: AS NOTED		DATE: JANUARY 1999	
SHEET No. E54 OF 56 SHEETS			

AS-BUILT
2/4/03

FED. ROAD DIST. NO.	STATE	FED. AID PROJ. NO.	FISCAL YEAR	SHEET NO.	TOTAL SHEETS
HAWAII	HAW.	STP-0300(66)	1998		

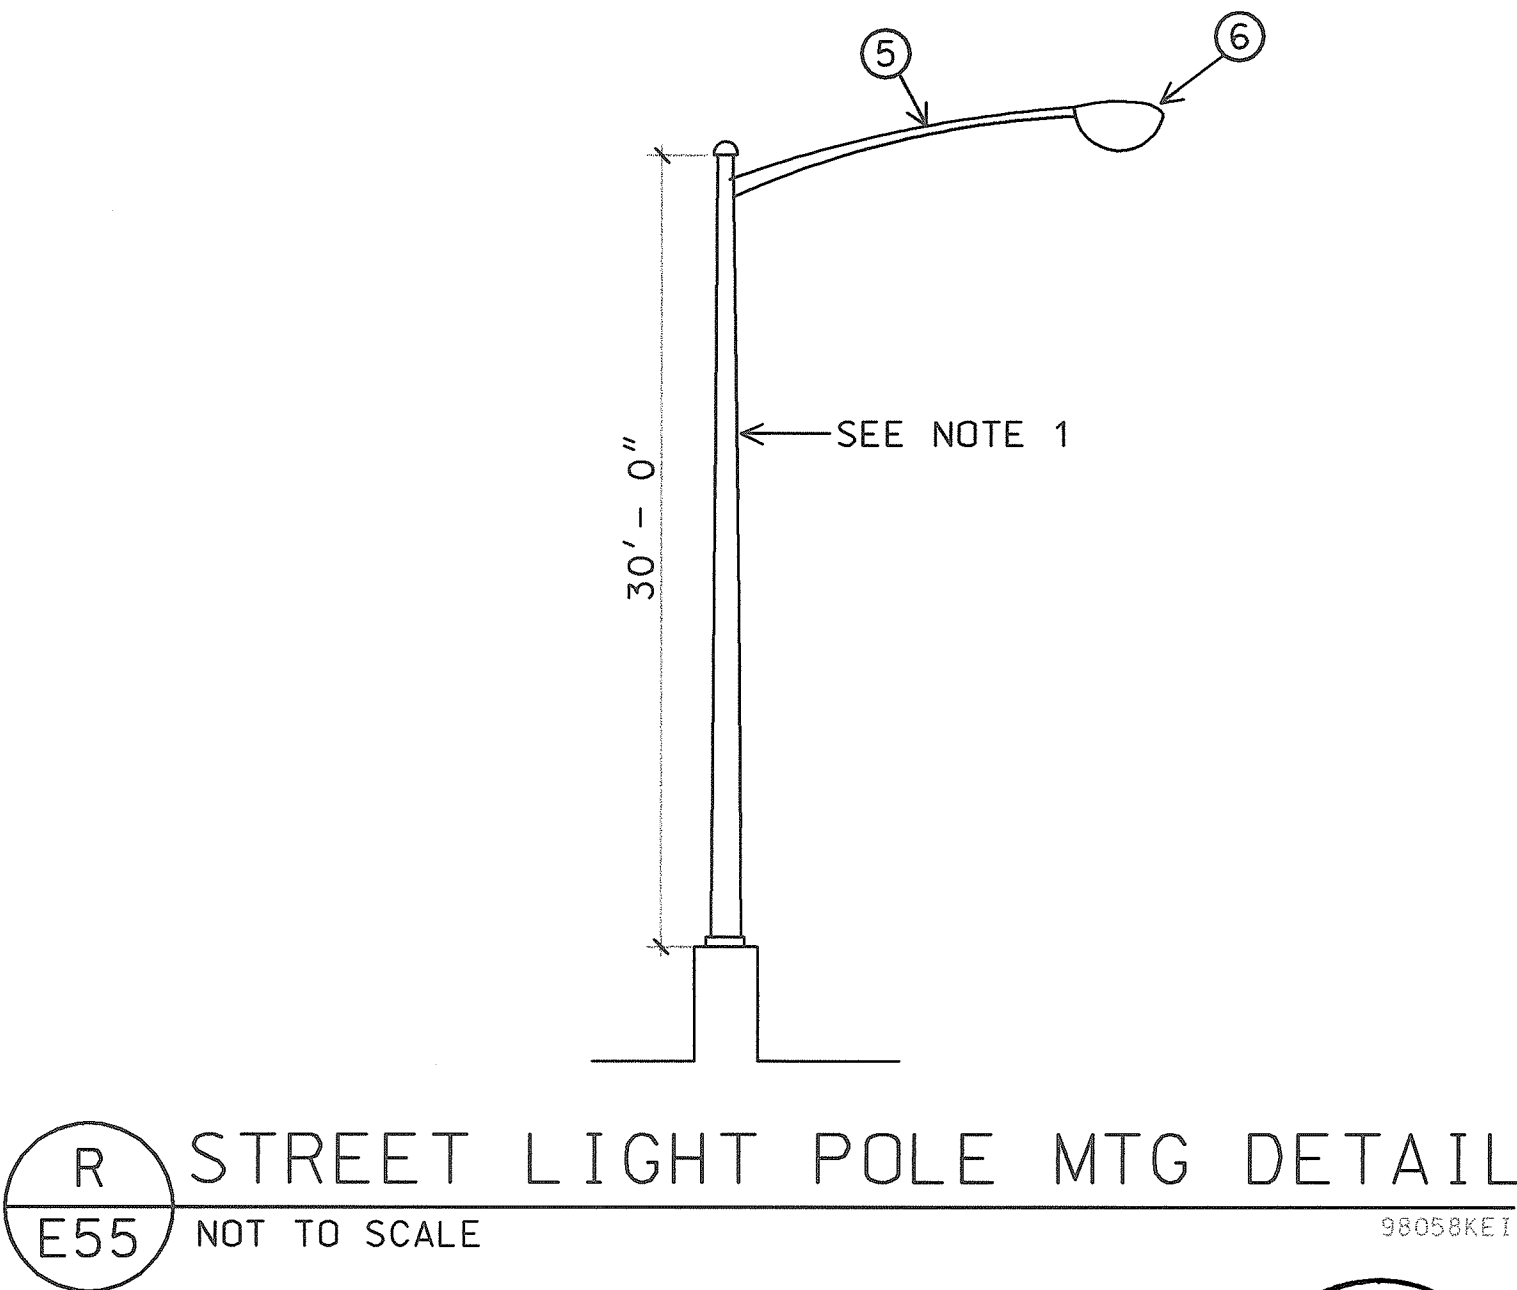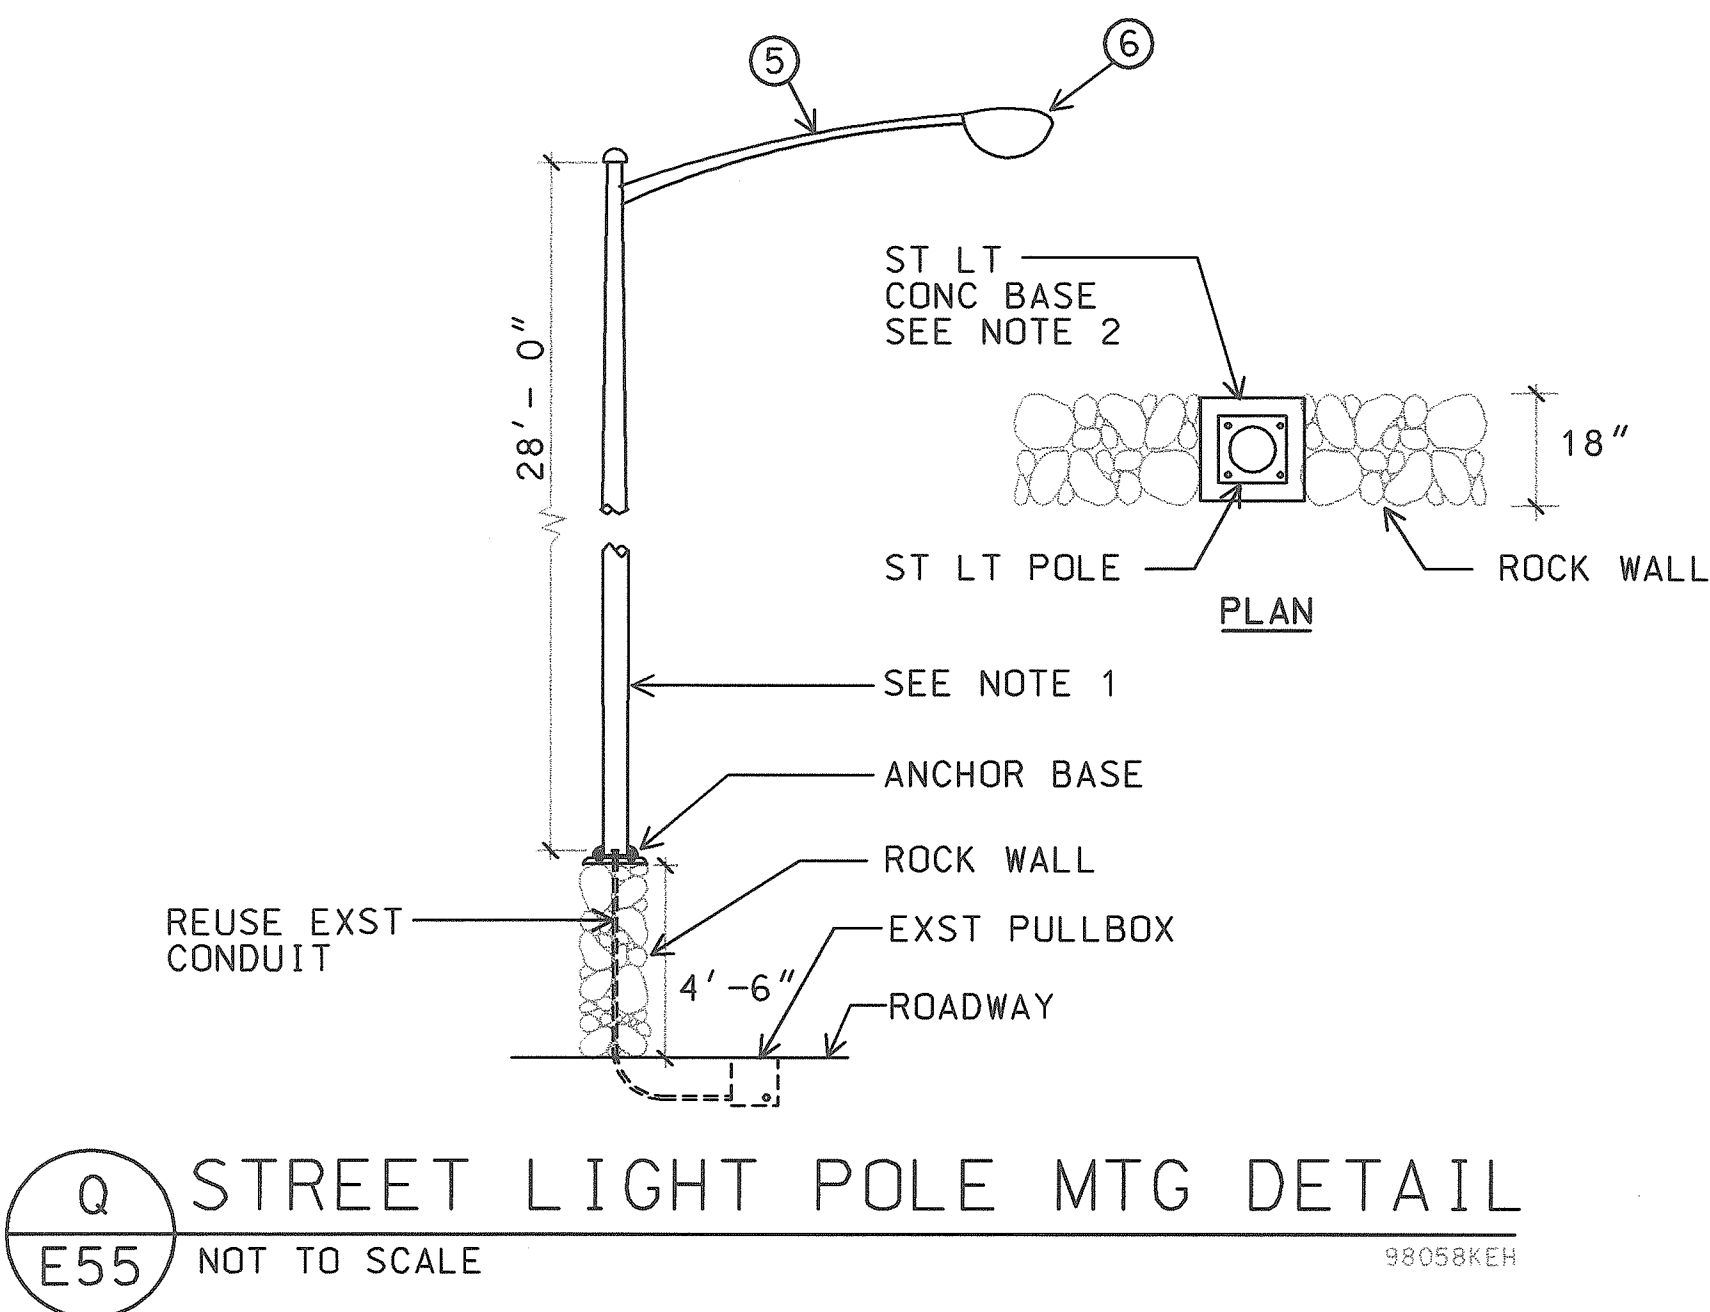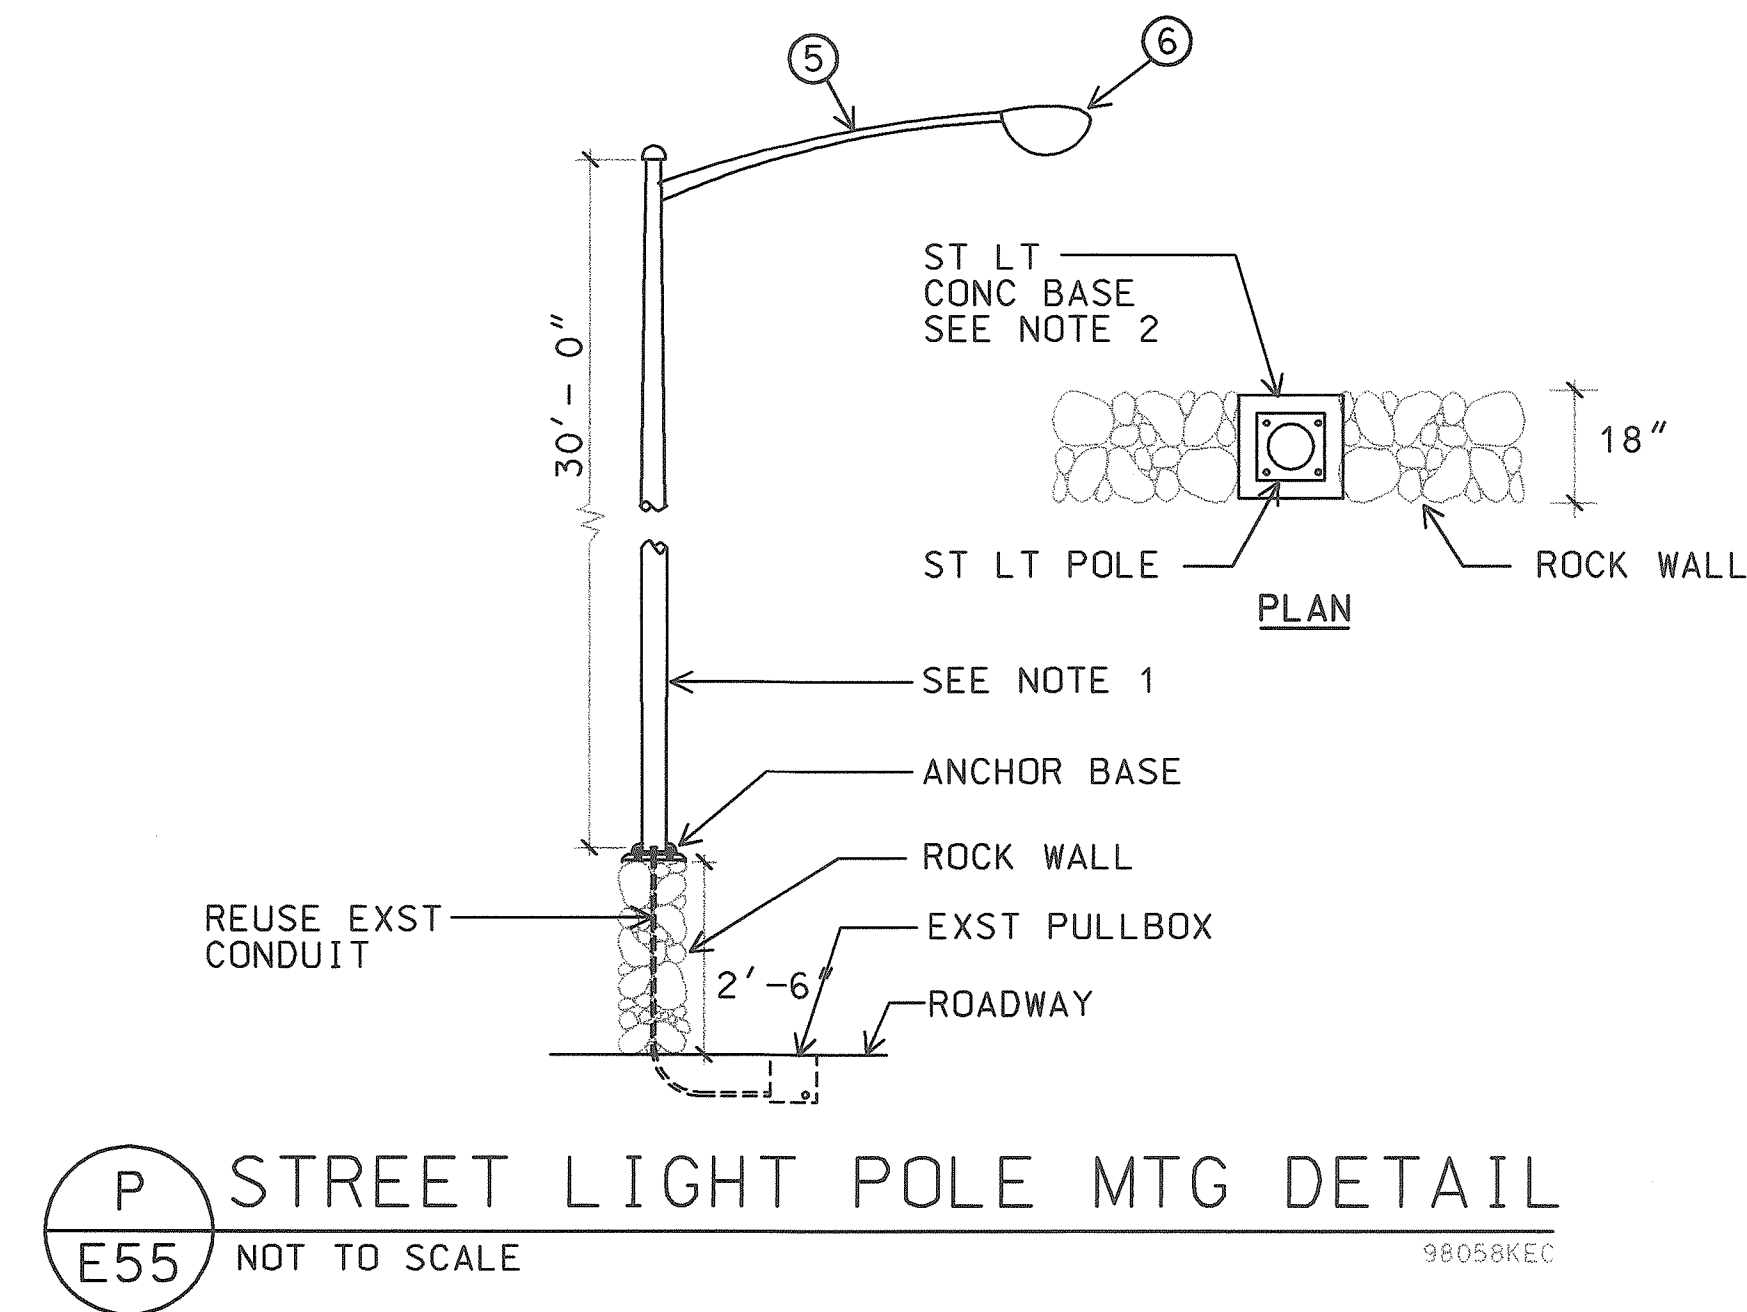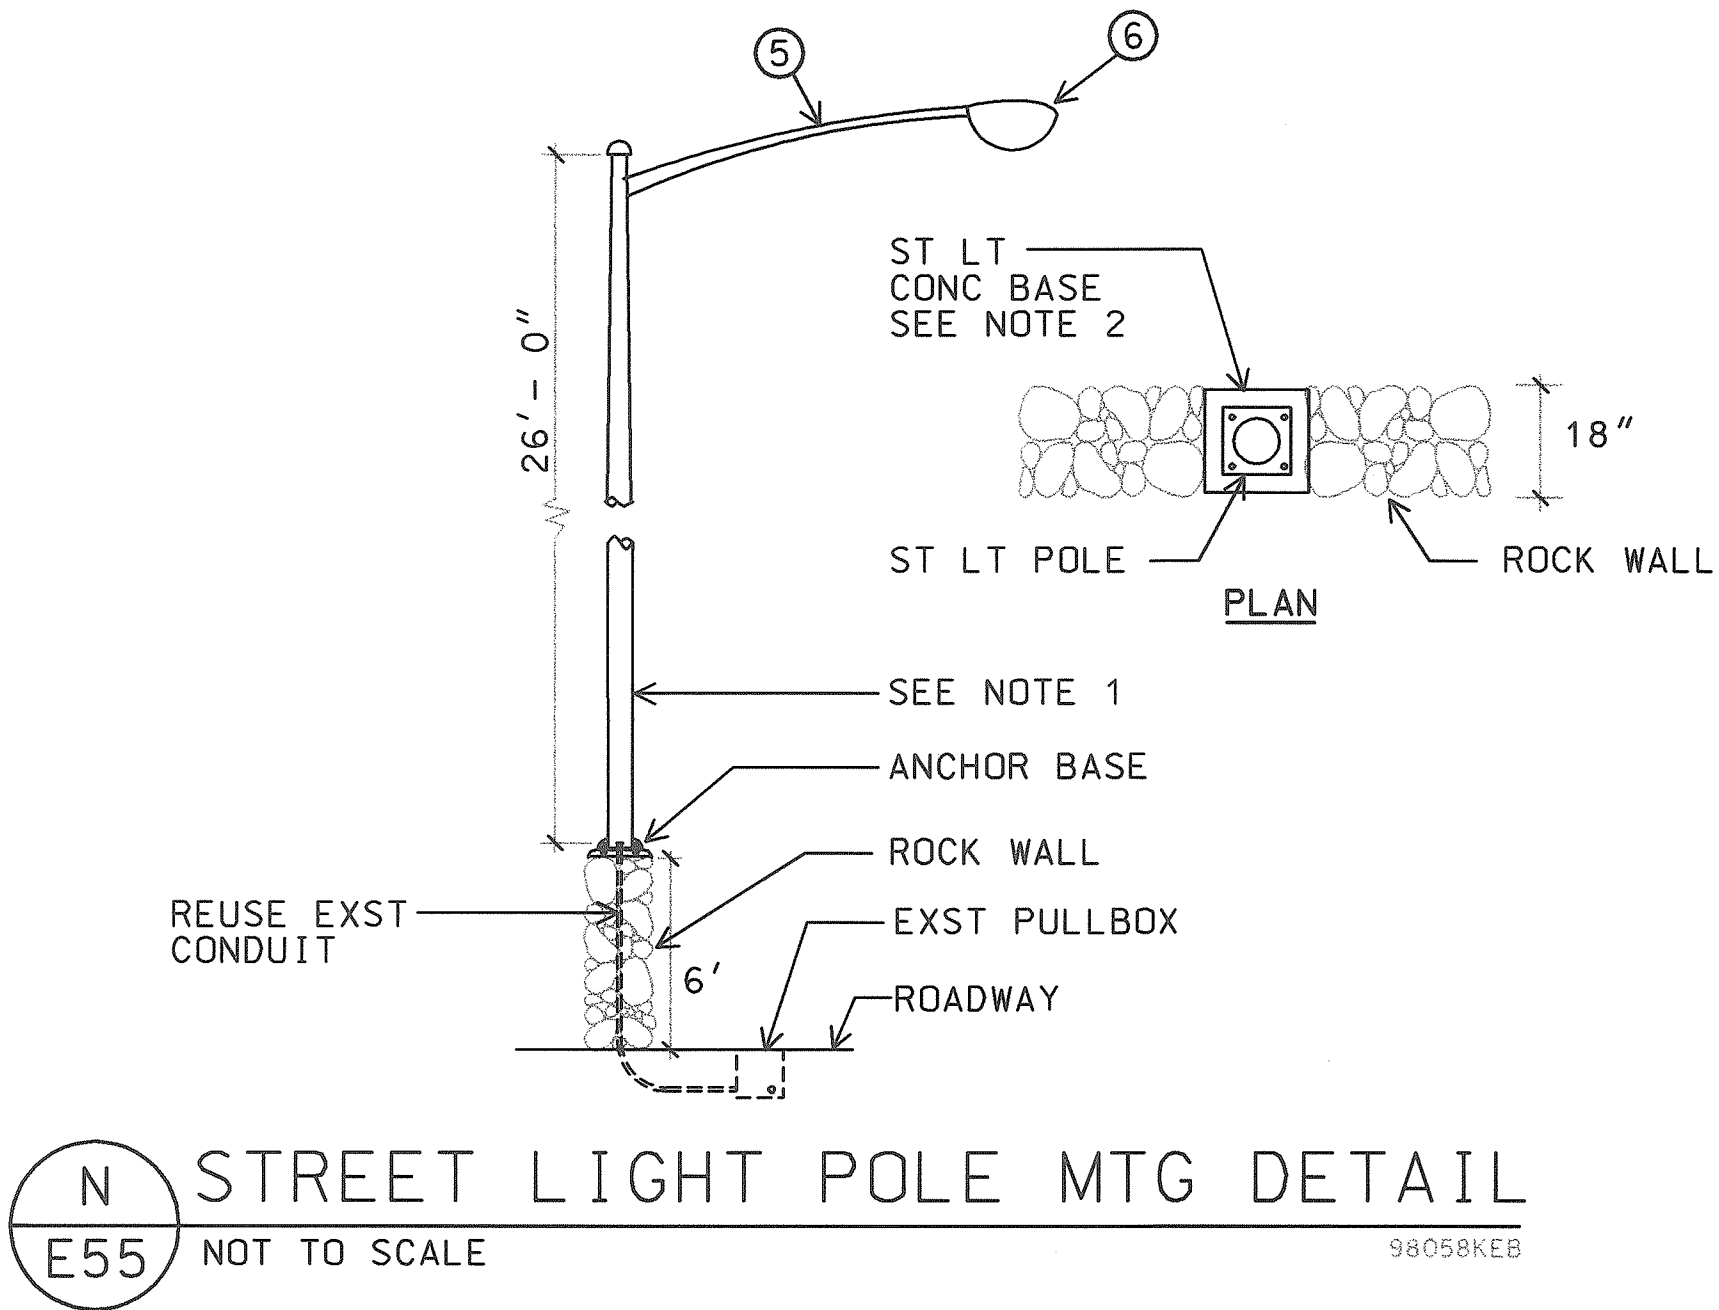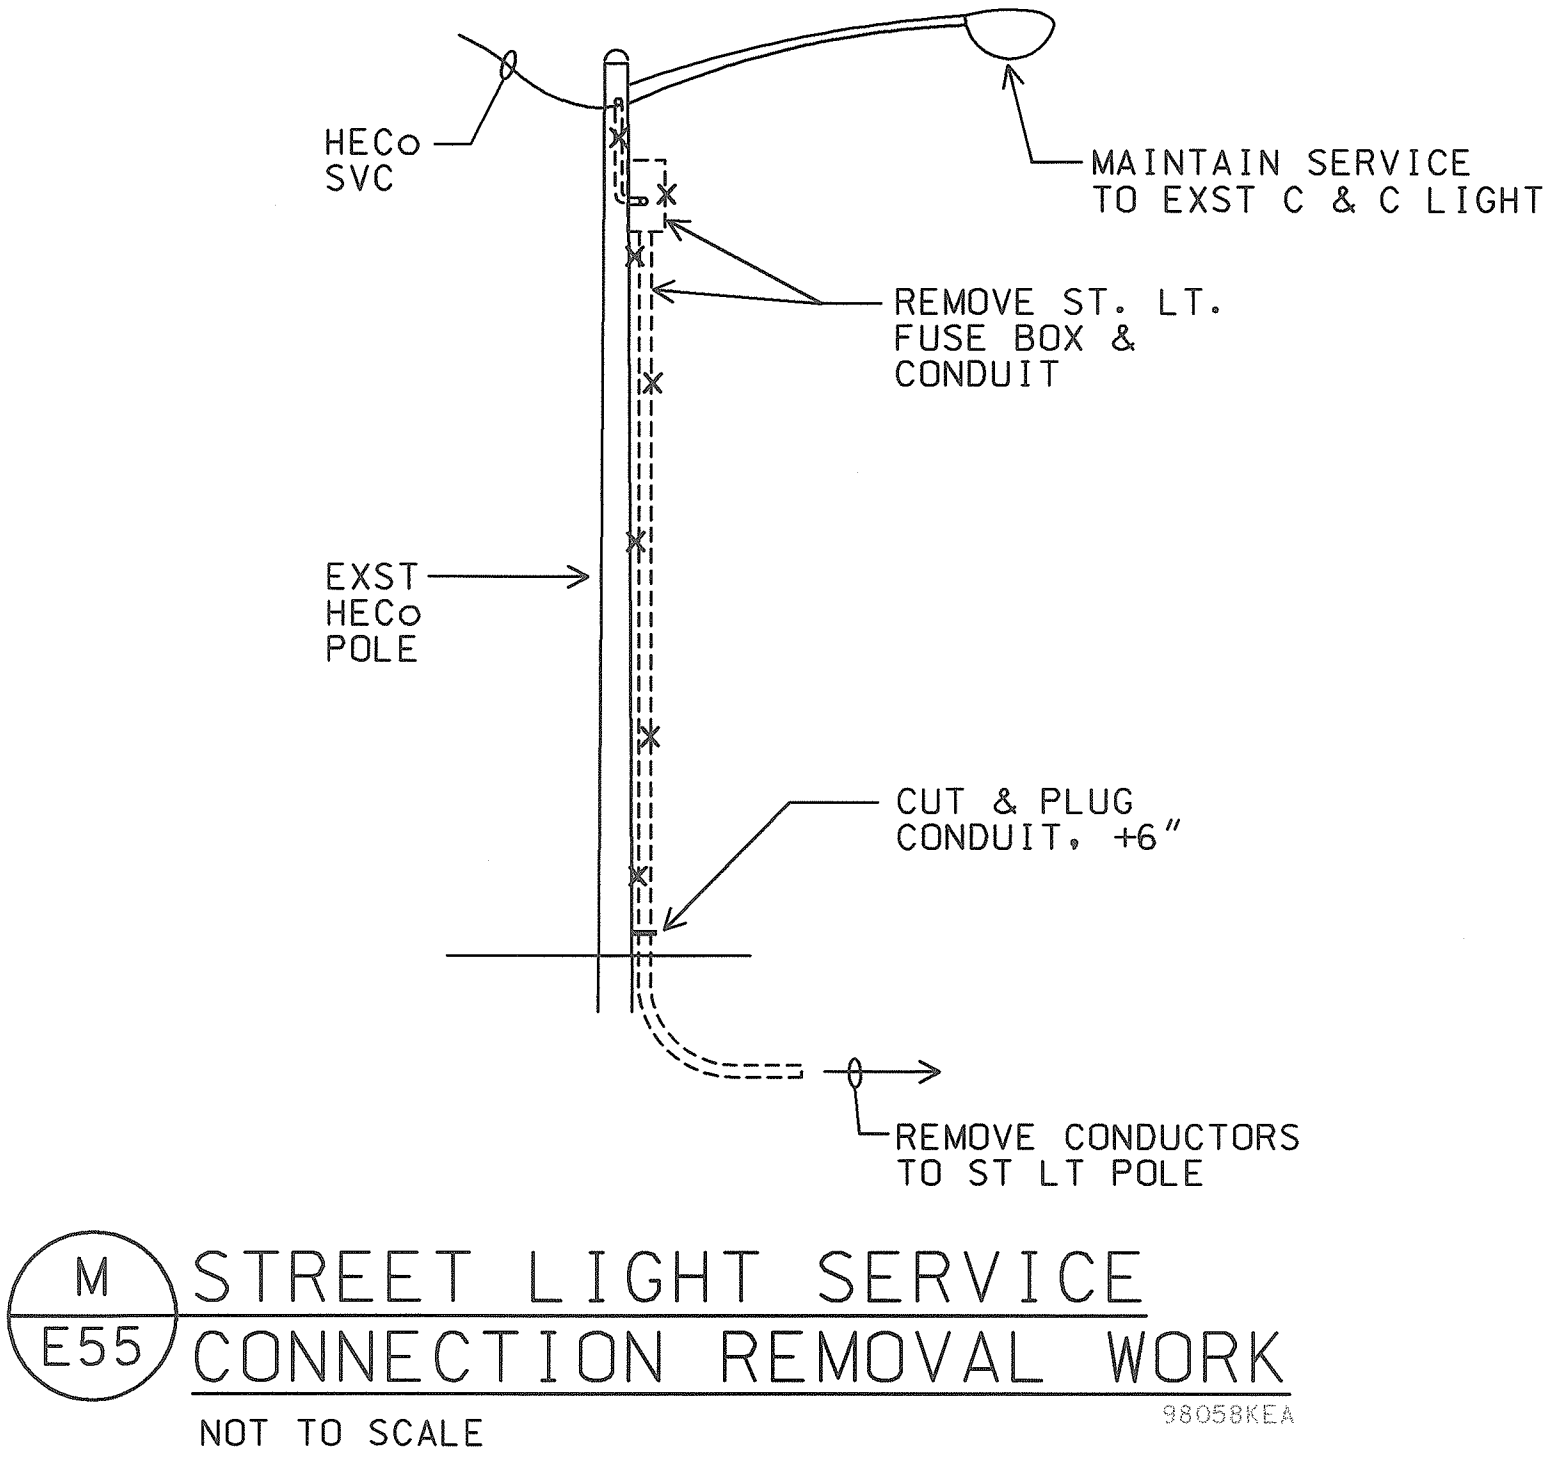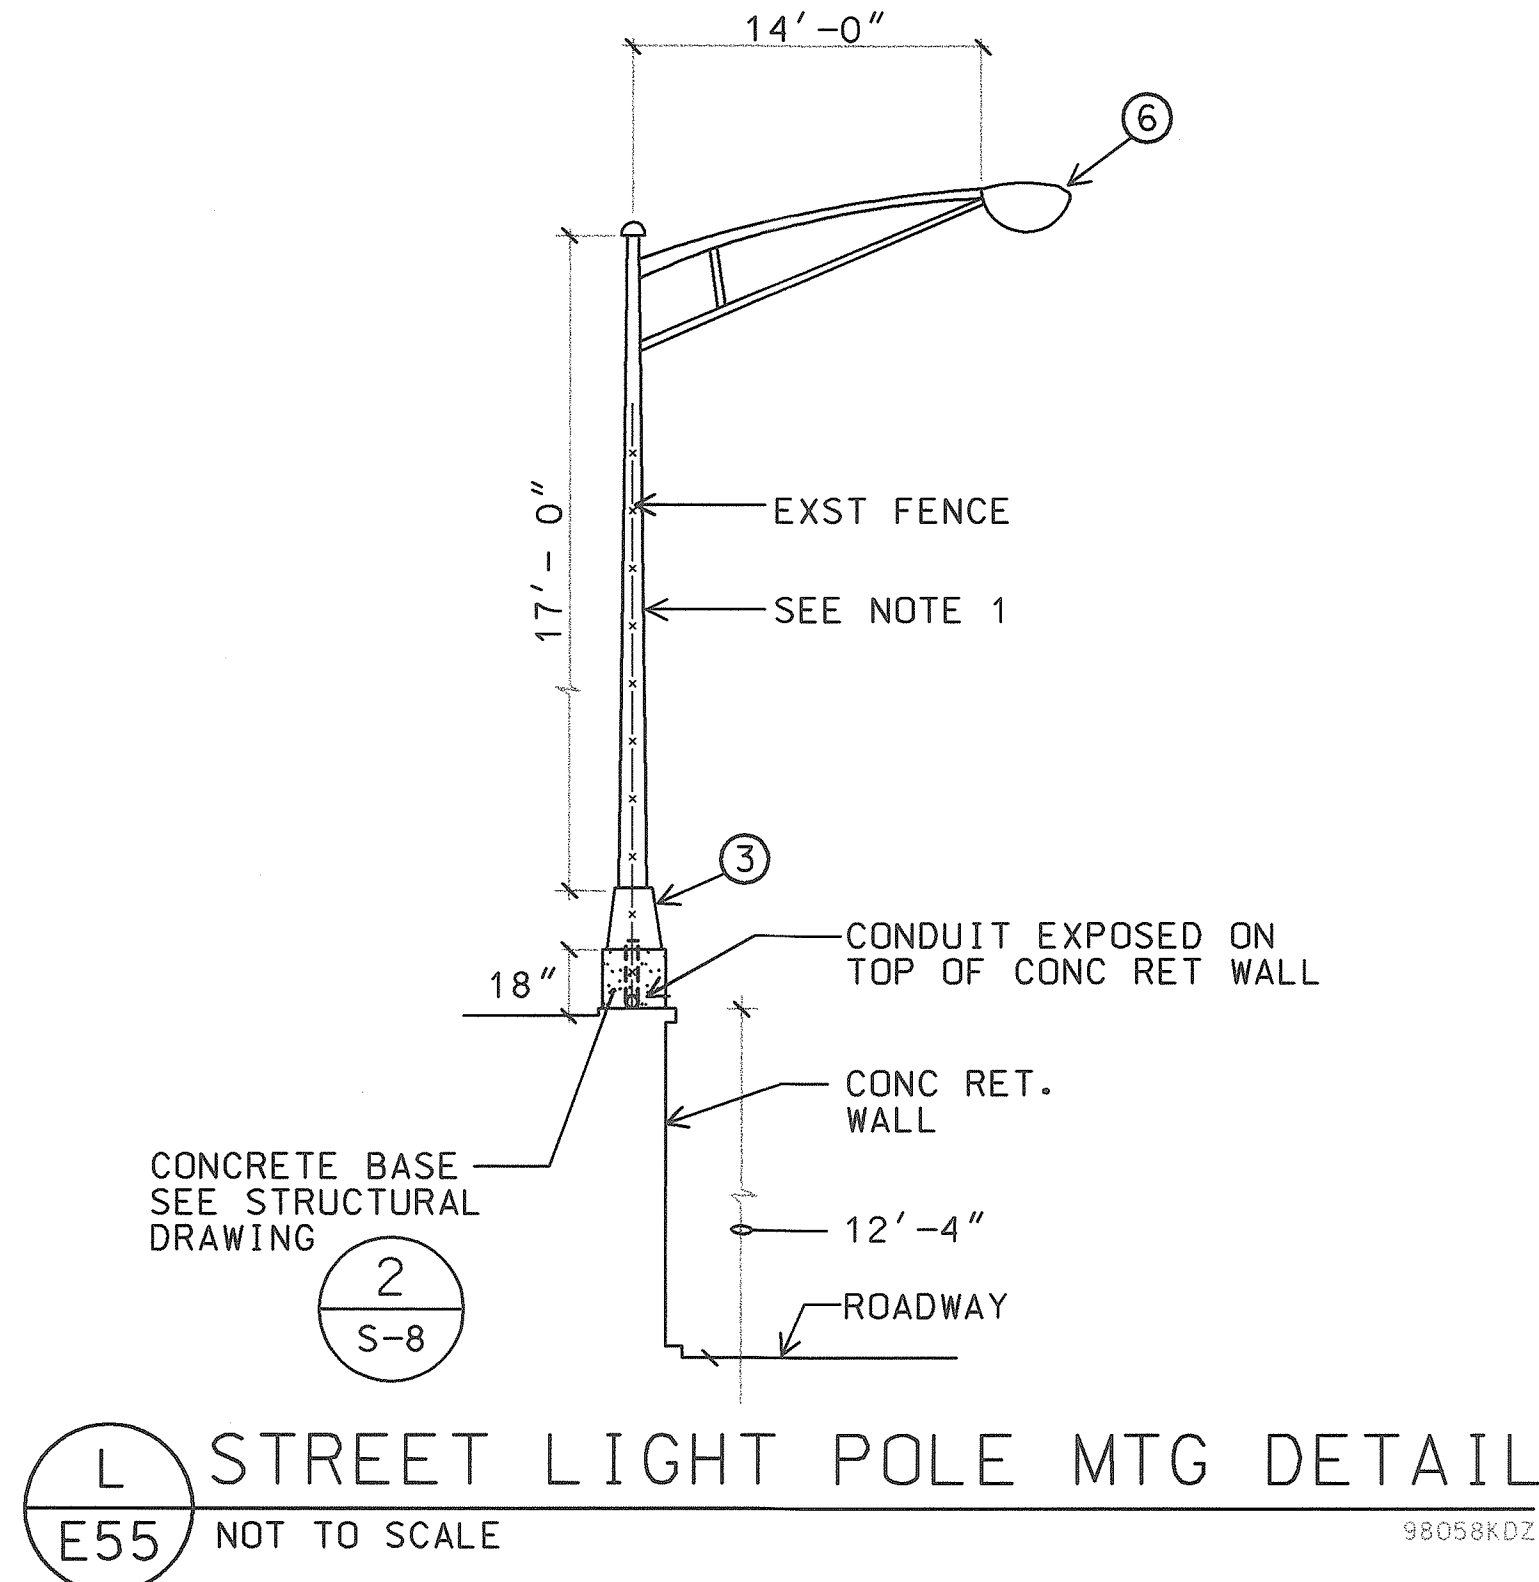

- NOTES:**
1. SATIN BRUSHED FINISH ALUMINUM POLE WITH INTERNALLY MOUNTED FACTORY INSTALLED VIBRATION DAMPER. MUST WITHSTAND 100 MPH WIND VELOCITY WITH 1.3 GUST FACTOR PER AASHTO & BE FREE FROM WHITE RUST.
 2. PEDESTAL TO MATCH EXISTING WALL. REPAIR WALL TO MATCH EXISTING CONDITION.

STATE OF HAWAII
DEPARTMENT OF TRANSPORTATION
HIGHWAYS DIVISION

STREET LIGHT POLE DETAILS

HIGHWAY LIGHTING SAFETY IMPROVEMENTS
INTERSTATE ROUTE H-1
KEEAUMOKU STREET TO AINAKOA AVE

PROJECT NO. STP-0300(66)

SCALE: AS NOTED DATE: JANUARY 1999


SHEET No. E55 OF 56 SHEETS

AS-BUILT
2/4/03
DATE

THIS WORK WAS PREPARED BY ME
OR UNDER MY SUPERVISION.
MK Engineers, Ltd.
DATE: 11/25/98



FED. ROAD DIST. NO.	STATE	FED. AID PROJ. NO.	FISCAL YEAR	SHEET NO.	TOTAL SHEETS
HAWAII	HAW.	STP-0300(66)	1998		

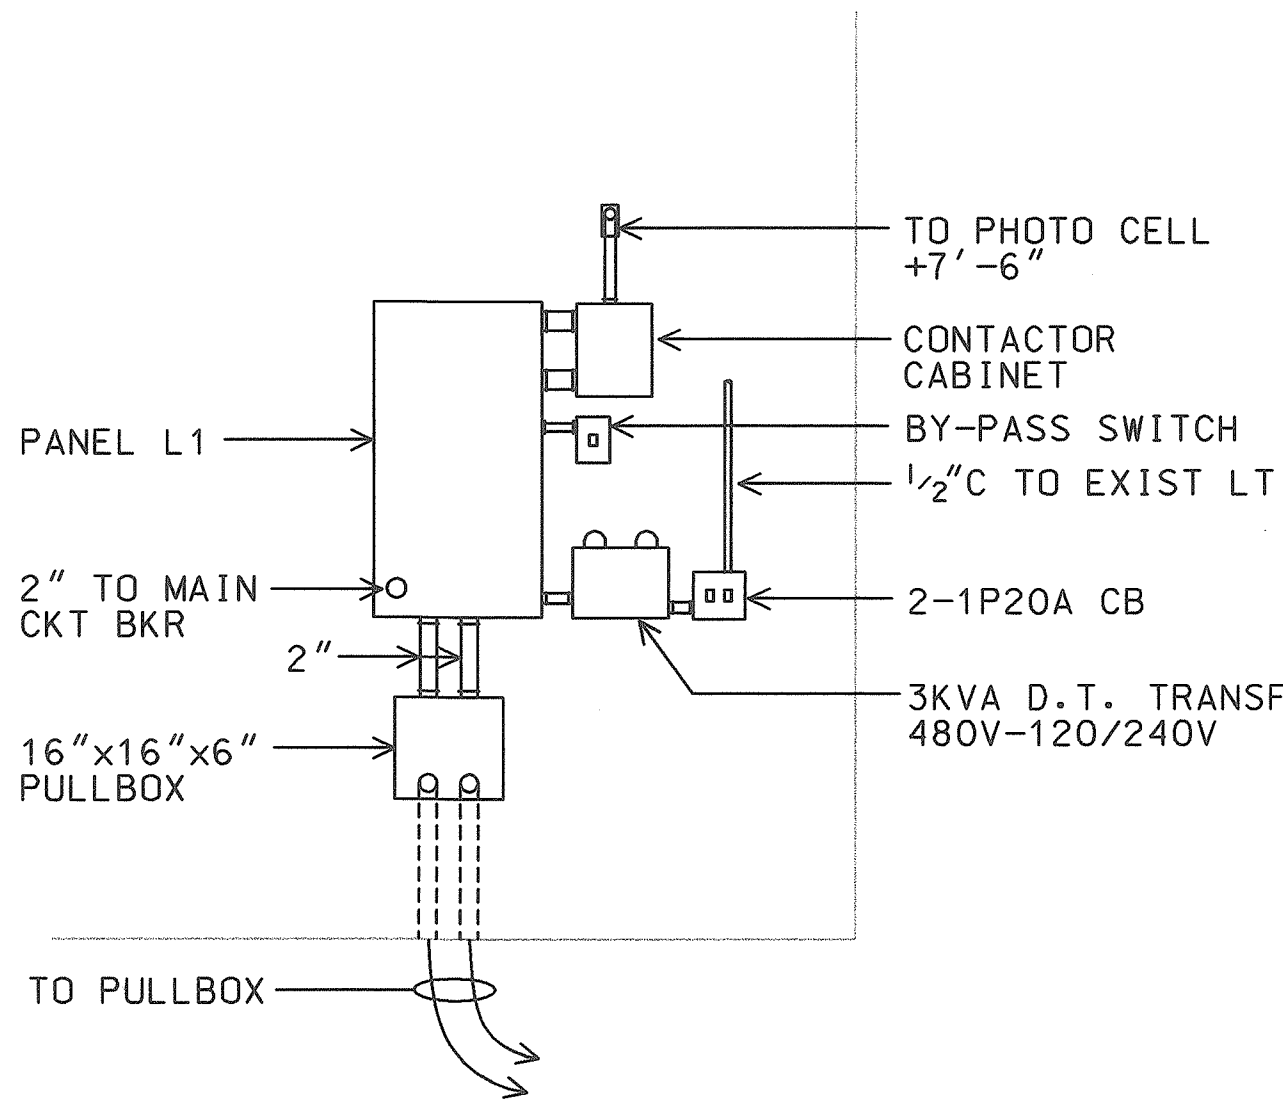


S56

ELEC APPARATUS ELEVATION

98058KEE

SCALE: 1/2" = 1'-0"

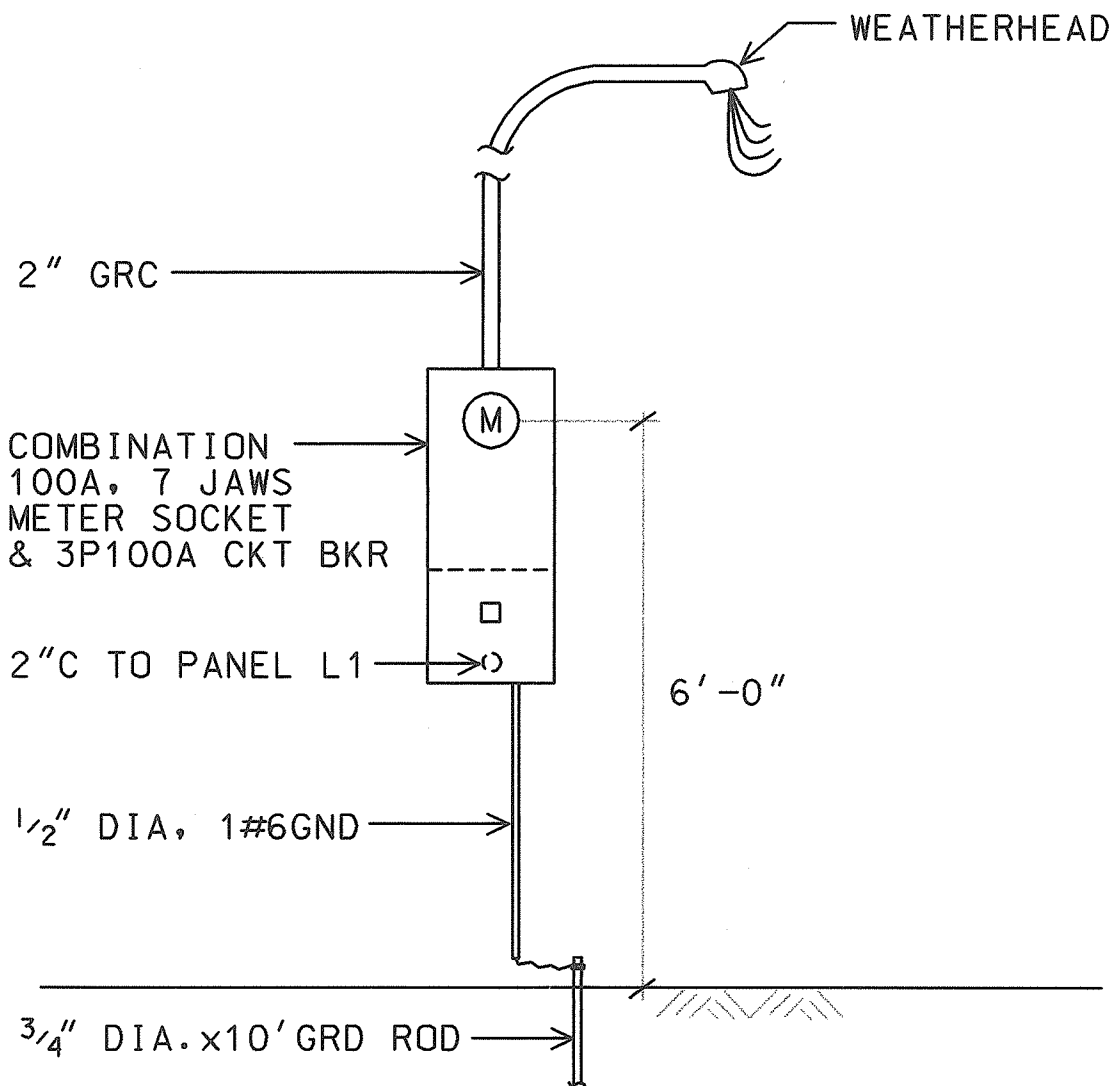


T56

SERVICE EQUIPMENT ELEVATION

98058KEE

SCALE: 1/2" = 1'-0"

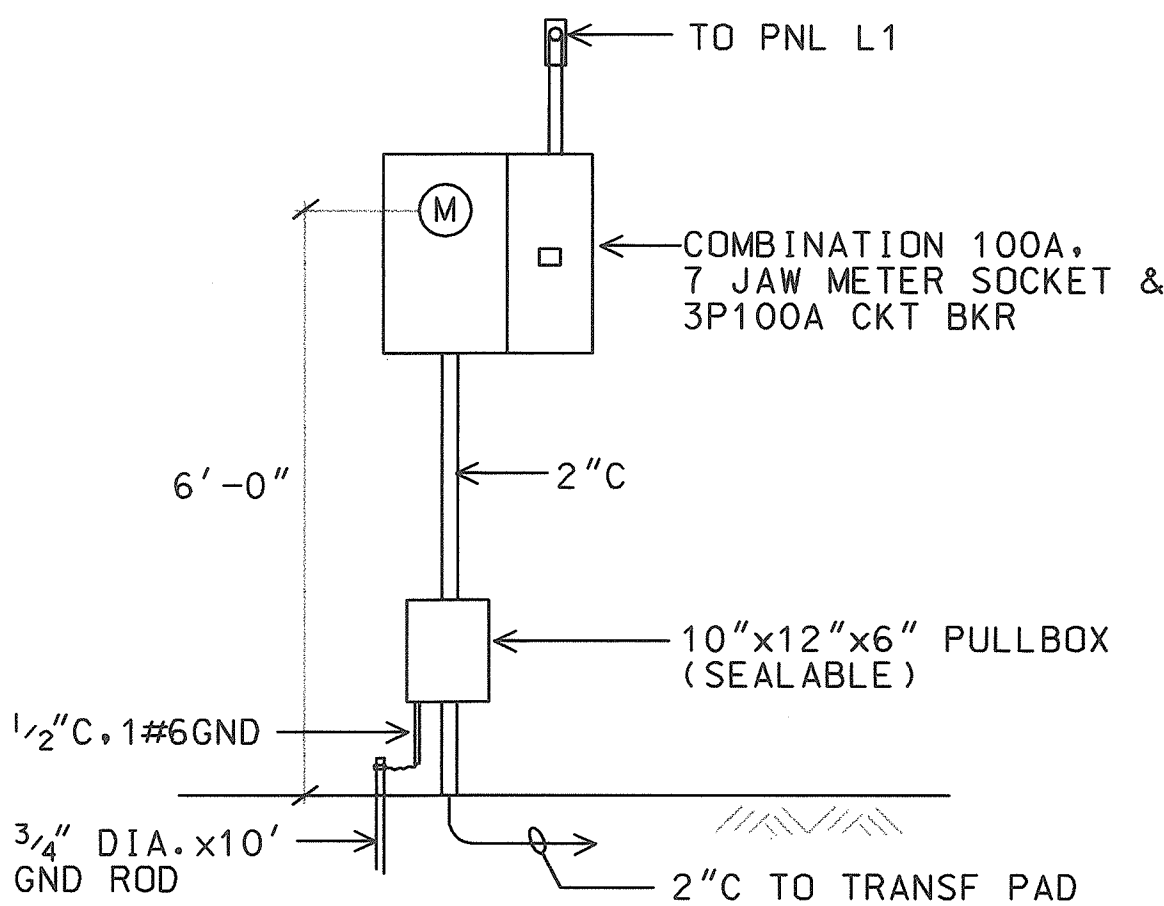


U56

SERVICE EQUIPMENT ELEVATION

98058KEF

SCALE: 1/2" = 1'-0"

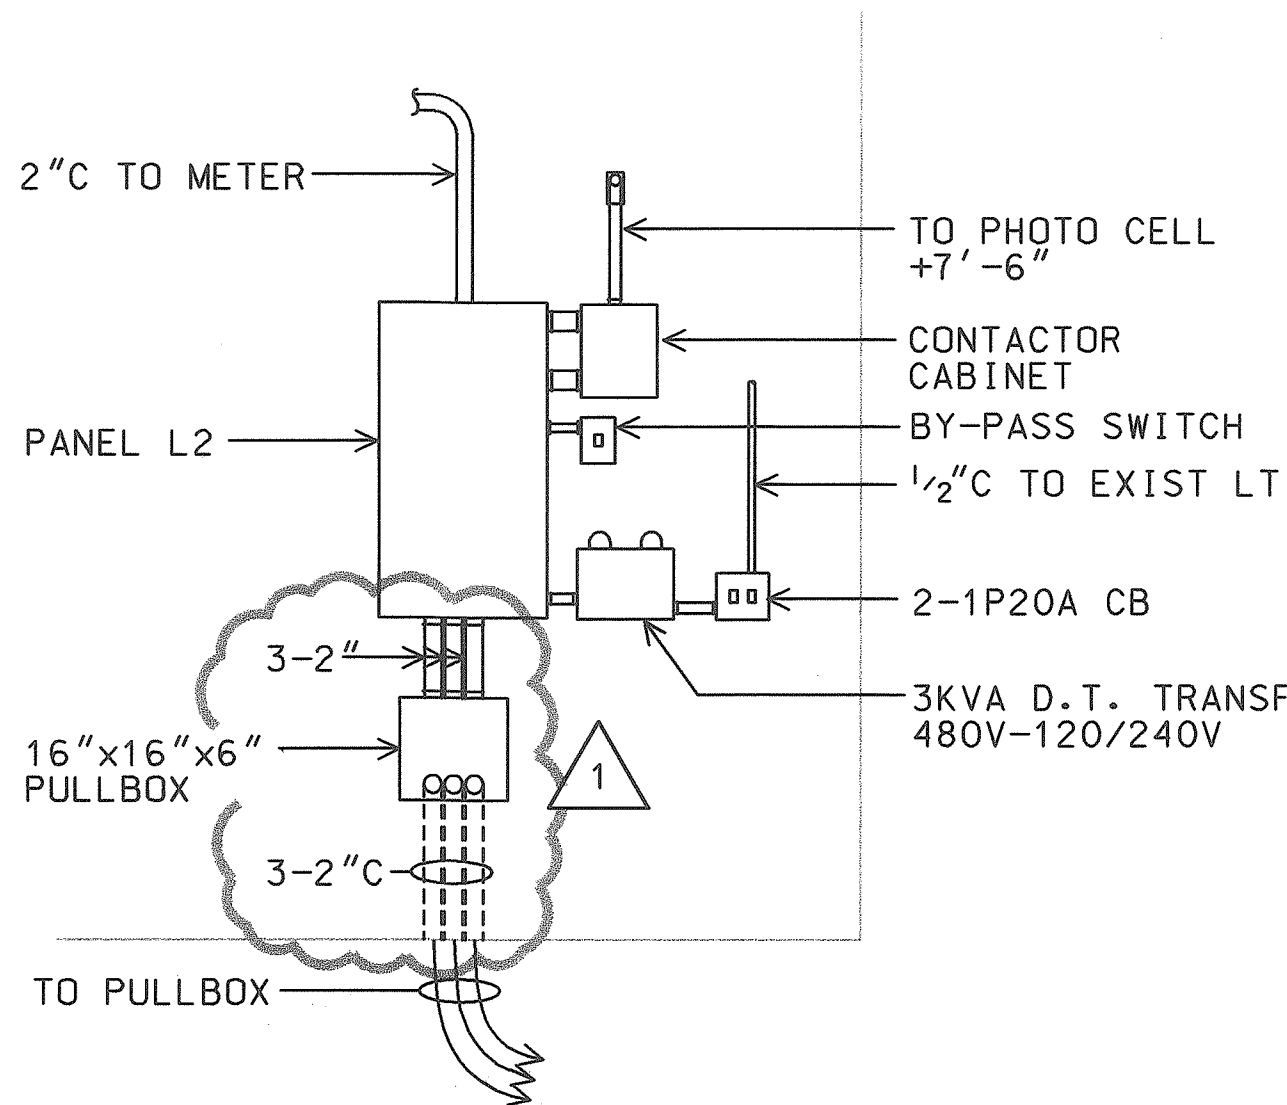


V56

ELEC APPARATUS ELEVATION

98058KEG

SCALE: 1/2" = 1'-0"

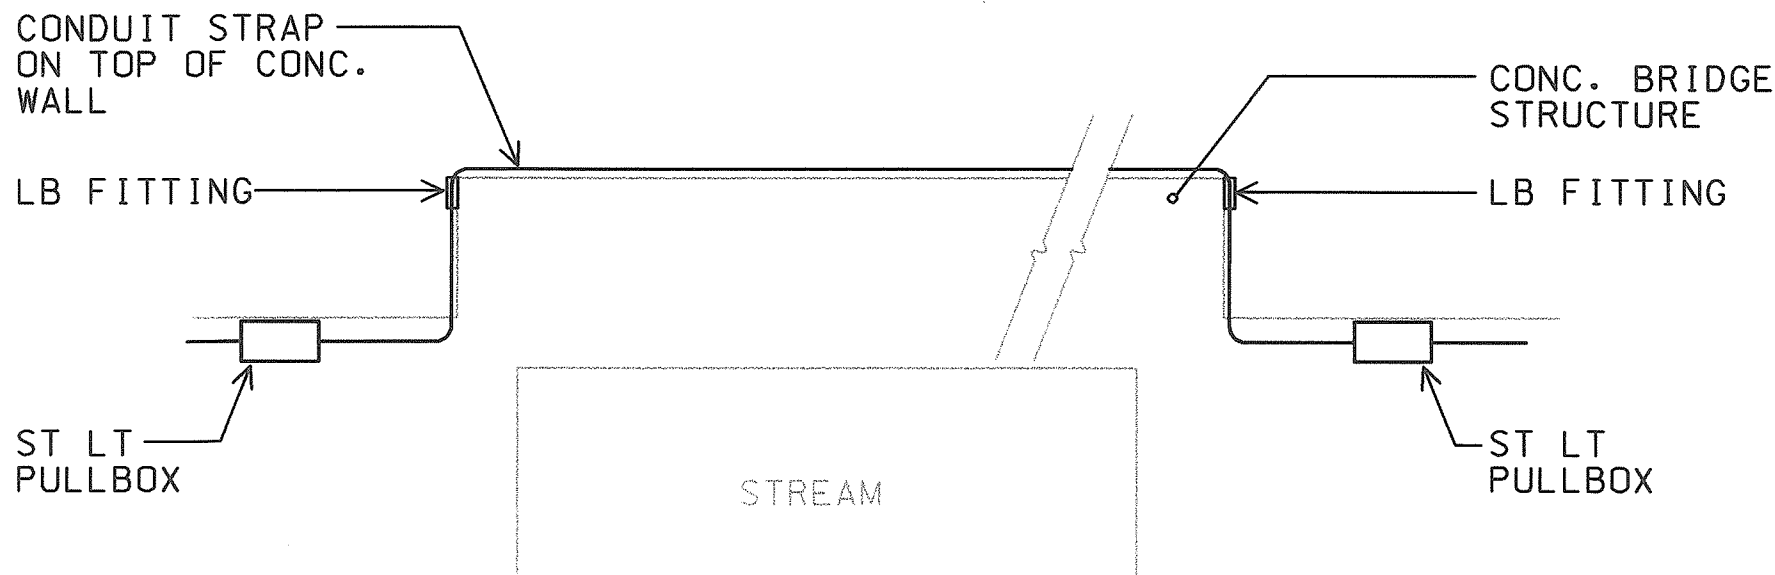


W56

CONDUIT MOUNTING DETAIL

98058KEJ

NOT TO SCALE

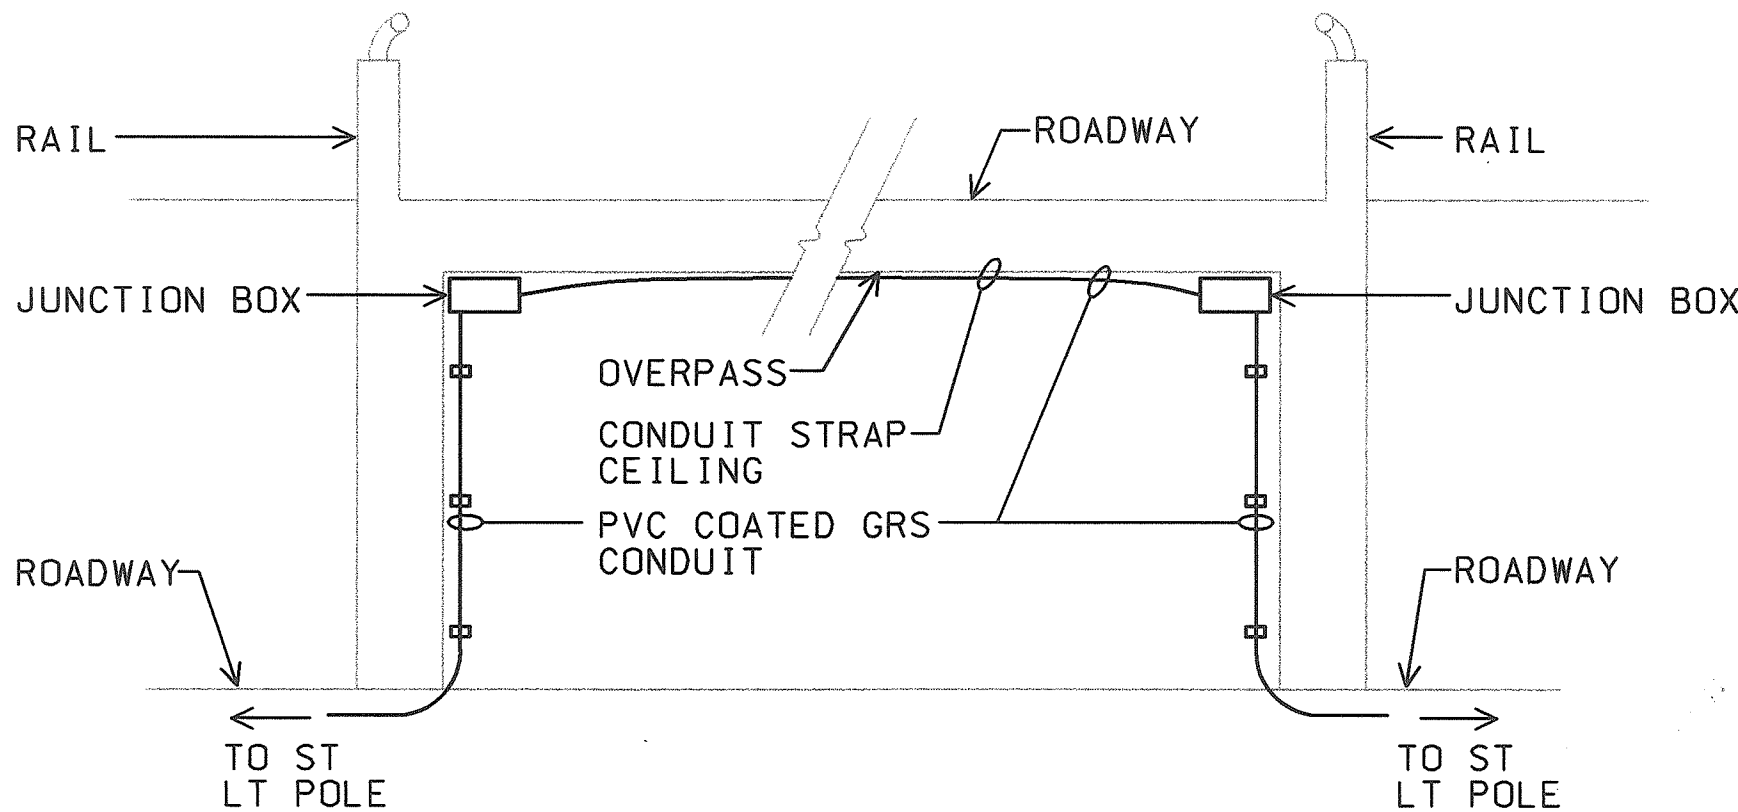

X56

JUNCTION BOX MOUNTING DETAIL


98058KEK

NOT TO SCALE

AS-BUILT

2/04/03

DATE

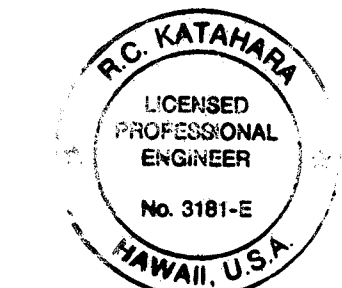

THIS WORK WAS PREPARED BY ME

OR UNDER MY SUPERVISION.

R.C. KATAHARA 11/25/98

MK ENGINEERS, LTD.

DATE	REV	DESCRIPTION
8/16/99	ADD 1-2"C	
STATE OF HAWAII		
DEPARTMENT OF TRANSPORTATION		
HIGHWAYS DIVISION		
ELEVATIONS & DETAILS		
HIGHWAY LIGHTING SAFETY IMPROVEMENTS		
INTERSTATE ROUTE H-1		
KEEAUMOKU STREET TO AINAKOA AVE		
PROJECT NO. STP-0300(66)		
SCALE: AS NOTED		DATE: JANUARY 1999
SHEET No. E56 OF 56 SHEETS		