• •	INDEX TO DRAWINGS
SHEET NO.	DESCRIPTION
l	TITLE SHEET
2	STANDARD PLANS SUMMARY SHEET
3-5	TYPICAL ROADWAY SECTIONS
6	NOTES
① 7-19	ROADWAY PLAN AND PROFILE
2 0	DRAINAGE DETAILS
3 - <u></u> 4 21 - 29	SIGNING & STRIPING PLAN AND DETAILS
30 - 34	STREET LIGHTING PLAN AND DETAILS
35 - 36	SIGNALIZATION PLAN AND DETAILS
37 - 49	CROSS SECTIONS
₽ West (1997)	
,	

Plan Sht. Nos. ©CO 17 S-1,©20 S-1, ©CO 25 S-1, & ©CO 25 S-2 are supplementary sheets to this project.

TOTAL SHEET COUNT after "AS BUILT" postings. 53 Sheets.


STATE OF HAWAII


TRANSPORTATION DEPARTMENT DIVISION HIGHWAYS

HONOLULU, HAWAII
"AS-BUILT"
PLANS FOR

IMPROVEMENTS ALONG PALI HIGHWAY NIOLOPA PLACE TO WAOKANAKA STREET PROJECT NO. F-061-1(23)

DISTRICT OF HONOLULU ISLAND OF OAHU

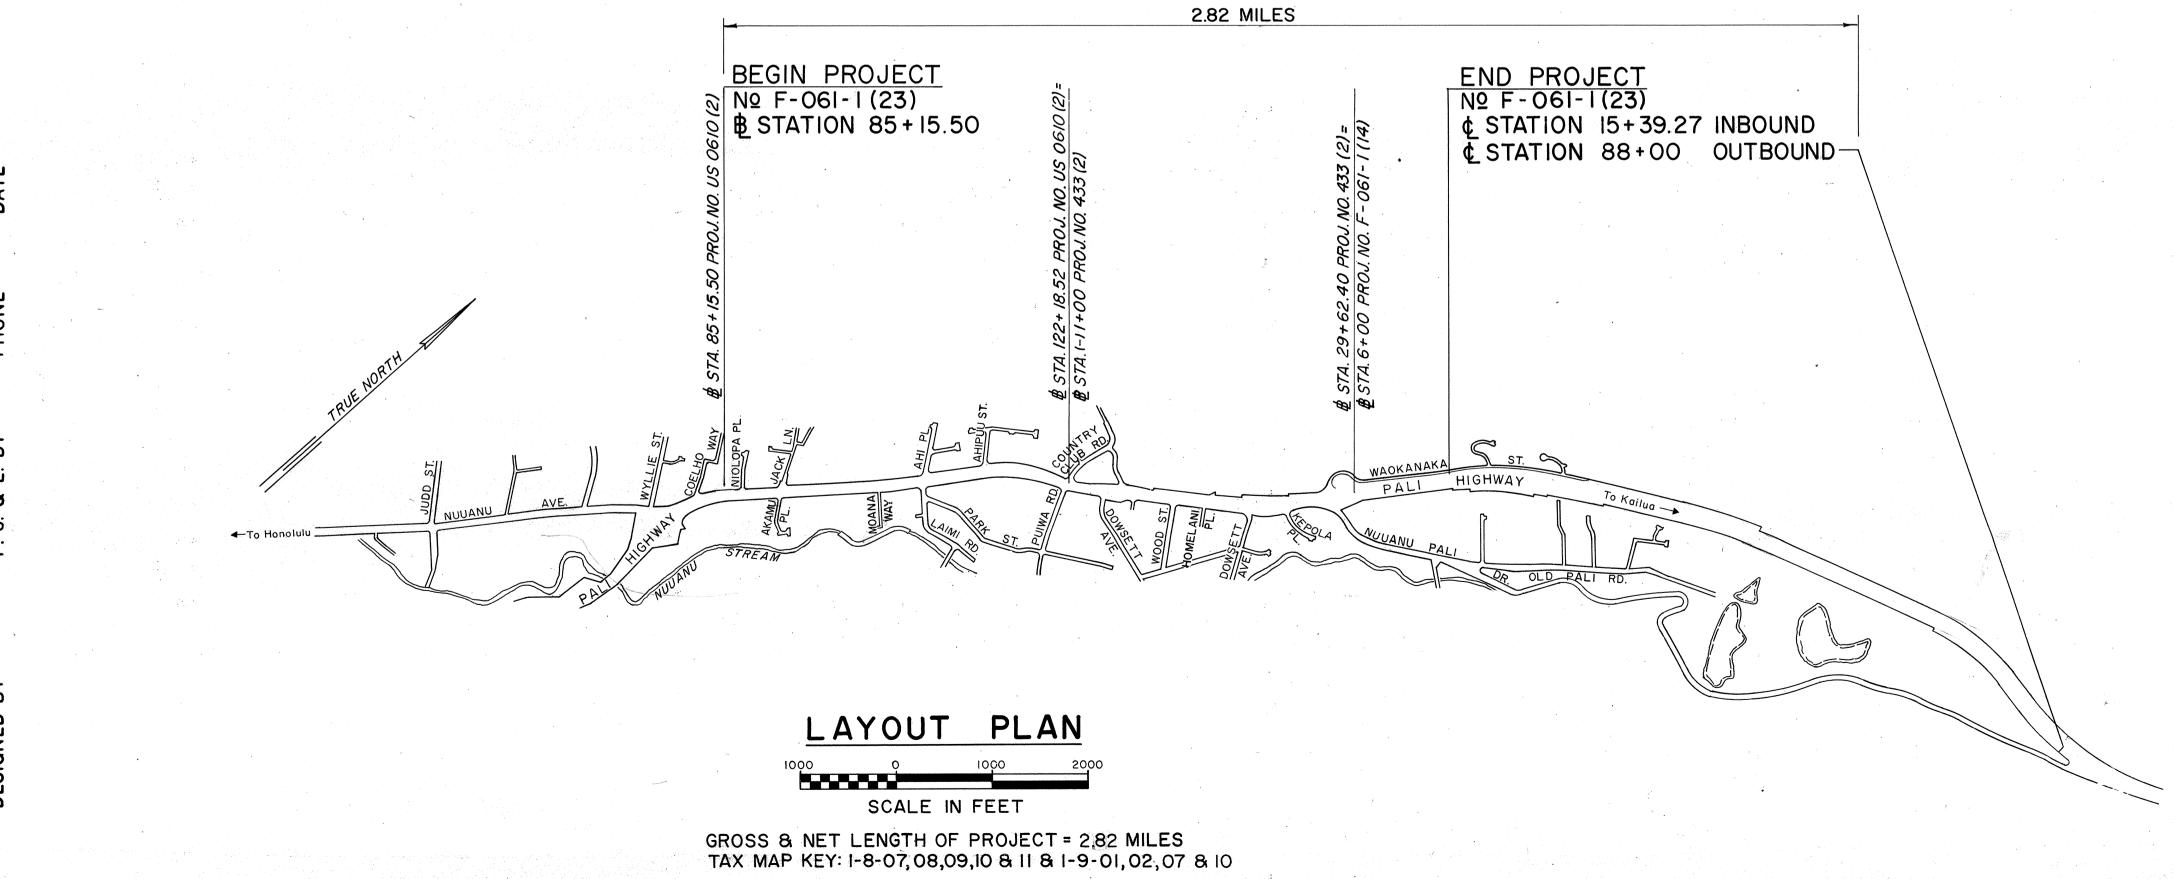

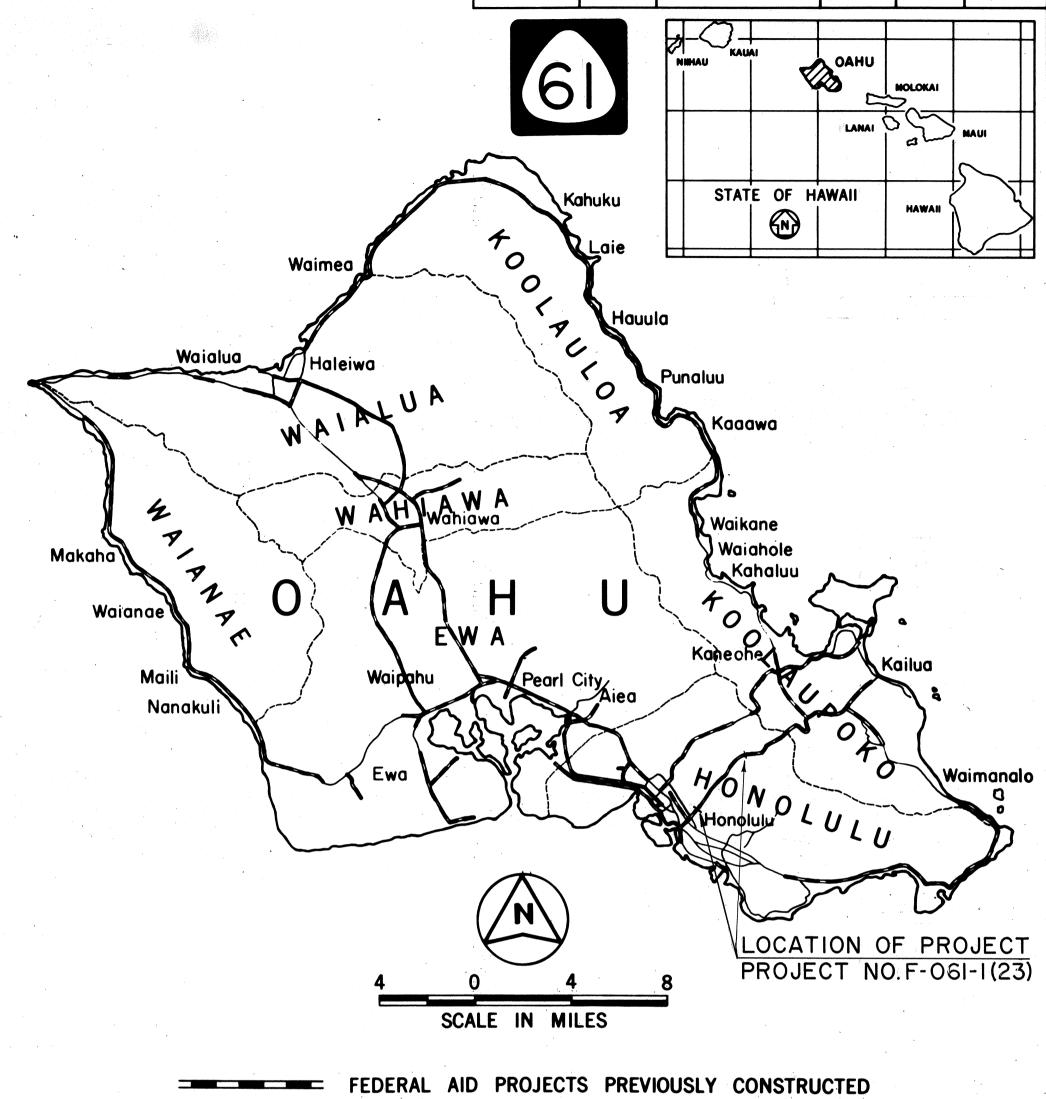

FED. ROAD DIST. NO.

FISCAL SHEET YEAR NO.

FED. AID PROJ. NO.

F-061-1(23)

OR UNDER CONSTRUCTION

DESIGN CLASSIFICATION 1987 ADT. ... 59,900 2002 ADT......62,100 DHV.....5,300 T......1.5 V_____35 & 45 MPH

CHANGES MADE DURING CONSTRUCTION HAVE BEEN INCORPORATED ON THESE PLANS EXCEPT CHANGES IN THE ORIGINAL THEORETICAL QUANTITIES.

Sidney & C- Te RESIDENT ENGINEER

DATE

DEPARTMENT OF TRANSPORTATION FEDERAL HIGHWAY ADMINISTRATION **APPROVED:**

DIVISION ADMINISTRATOR

DEPARTMENT OF TRANSPORTATION STATE OF HAWAII **APPROVED:** DIR. OF TRANSPORTATION