1	INDEX TO DRAWINGS
SHEET NO.	DESCRIPTION
	TITLE SHEET
2	GENERAL NOTES & QUANTITY SCHEDULE
3	TYPICAL SECTION & DETAILS
4 - 8	PLAN
9 - 19	TYPICAL, MISCELLANEOUS & STANDARD BARRICADES & GUARD RAIL DETAILS
20-28	DRAINAGE DETAILS
29 - 45	SIGNING, PAVEMENT MARKING & HIGHWAY LIGHTING PLANS & DETAILS

548-753 PHONE

P. S. & E. BY

NISHIMURA DESIGNED BY



STATE OF HAWAII



DEPARTMENT OF TRANSPORTATION

HIGHWAYS DIVISION

"AS-BUILT"

PLANS FOR

CIKELIKE HIGHWAY


GUARD RAIL AND SHOULDER IMPROVEMENTS

KALIHI STREAM BRIDGE TOWARD KAHEKILI HIGHWAY

PHASE I

PROJECT NO. LT-0-06-79

DISTRICT OF HONOLULU ISLAND OF OAHU

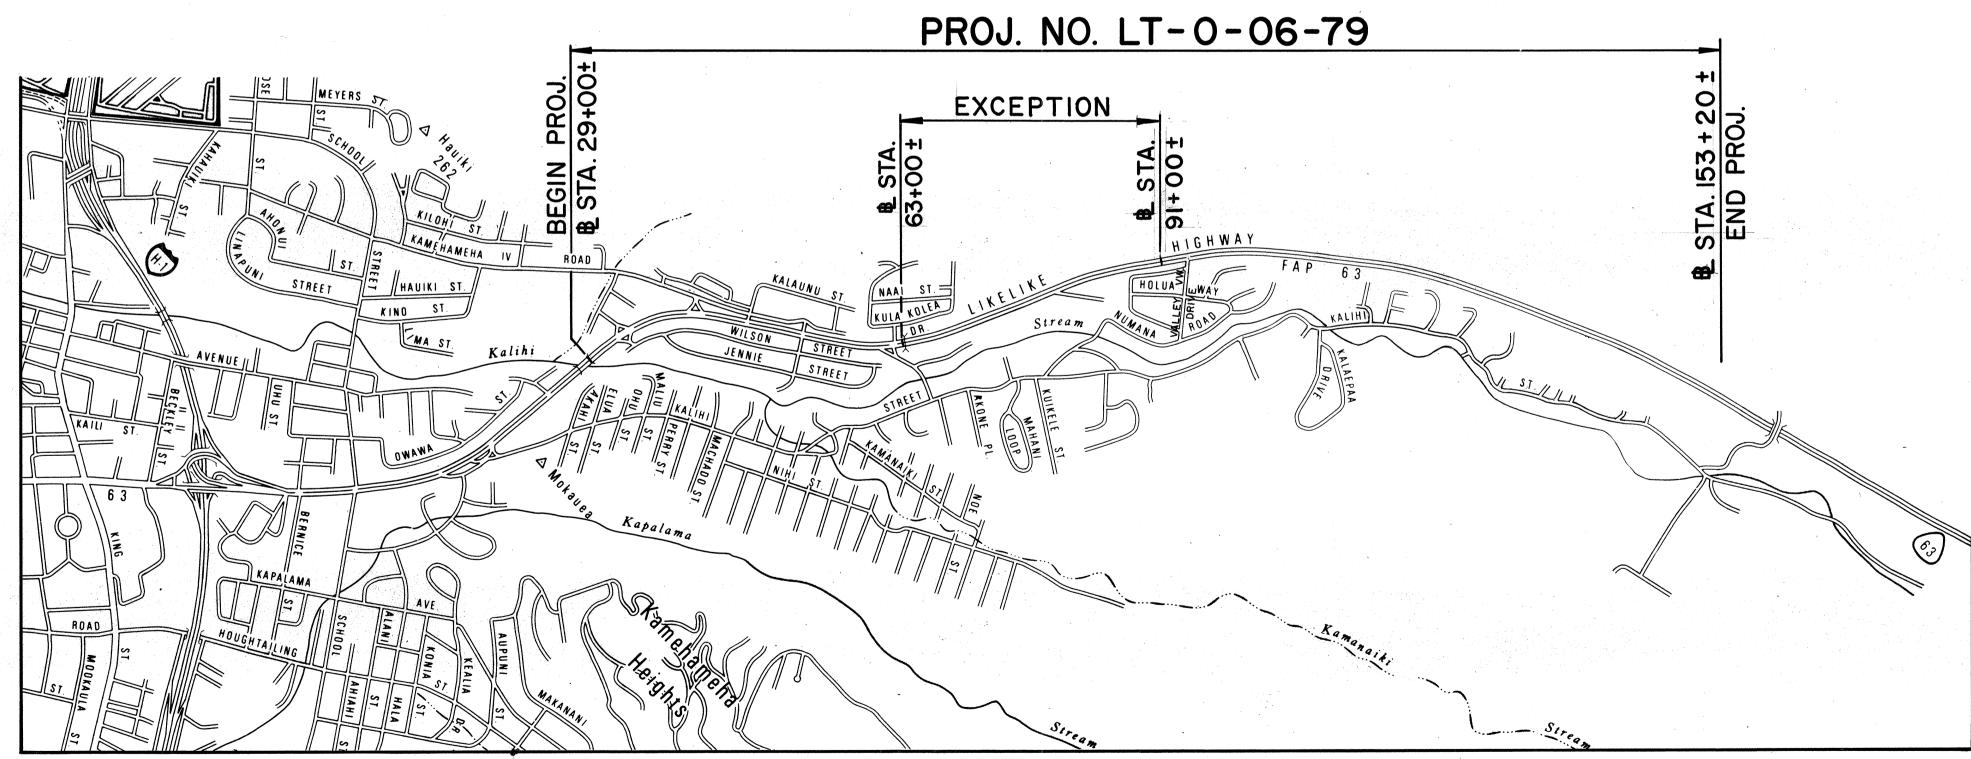

Waidlad

Wai


FED. ROAD DIST. NO.

FEDERAL AID PROJECTS PREVIOUSLY CONSTRUCTED OR UNDER CONSTRUCTION

ALL CHANGES MADE DURING CONSTRUCTION HAVE BEEN INCORPORATED ON THESE PLANS IN RED EXCEPT CHANGES IN THE ORIGINAL THEORETICAL QUANTITIES FOR ACTUAL QUANTITIES, REFER TO PROJECT LEDGER AND/OR COMPUTATION BOOK.

RESIDENT ENGINEER

11/12/8/ DATE

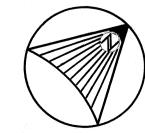

LAYOUT PLAN

GROSS LENGTH OF PROJECT EXCEPTION
NET LENGTH OF PROJECT

2.35 MI. .53 MI. 1.82 MI.



