·	
INDEX TO DRAWINGS	
SHEET NO.	DESCRIPTION
1	TITLE SHEET
2	GENERAL NOTES
3	ELECTRICAL SYMBOL LIST, ONE-LINE DIAGRAM,
	GENERAL NOTES
4	ELECTRICAL SITE PLANS #1 & #2
5	ELECTRICAL SITE PLANS #3 & #4
6	ELECTRICAL SITE PLANS #5 & #6
7	ELECTRICAL SITE PLANS #7 & #8
8	ELECTRICAL SITE PLANS #9 & #10
<b>①</b> 9	ELECTRICAL SITE PLAN #11, GUARD RAIL DETAILS
10	HANDHOLE DETAILS
11	MISCELLANEOUS DETAILS, LIGHT STANDARD
	SCHEDULE
12	STREET LIGHT POLE DETAILS
. 13	ELECTRICAL SERVICE EQUIPMENT ENCLOSURE
A - N	
, '	

Plan Sheet No. © C.O.9SI is a Supplementary Sheet to this Project.
TOTAL SHEET COUNT after "AS-BUILT" posting 14 Sheets

STATE OF HAWAII

## DEPARTMENT OF TRANSPORTATION HIGHWAYS DIVISION HONOLULU, HAWAII

"AS-BUILT"

PLANS FOR


LIKELIKE HIGHWAY


HIGHWAY LIGHTS

WILSON TUNNEL VIEW DRIVE TO VALLEY

PROJECT NO. 63A-02-90

HONOLULU OAHU

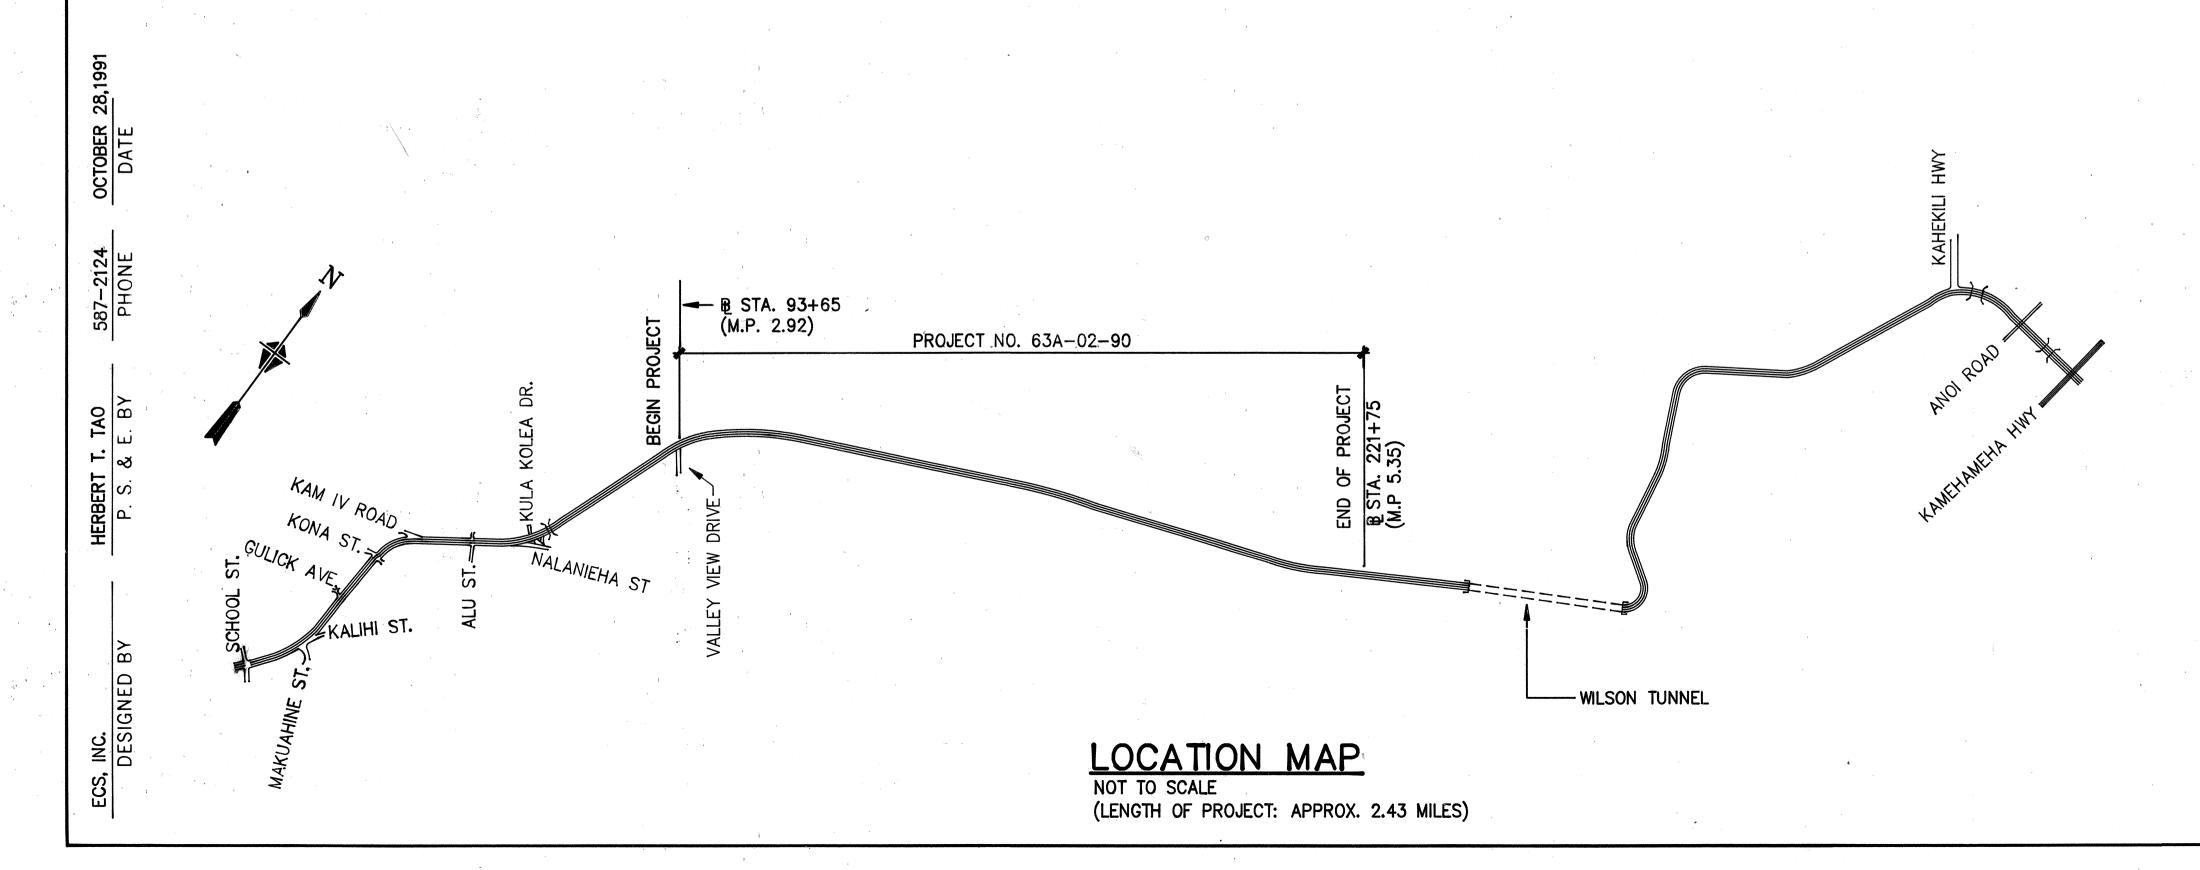

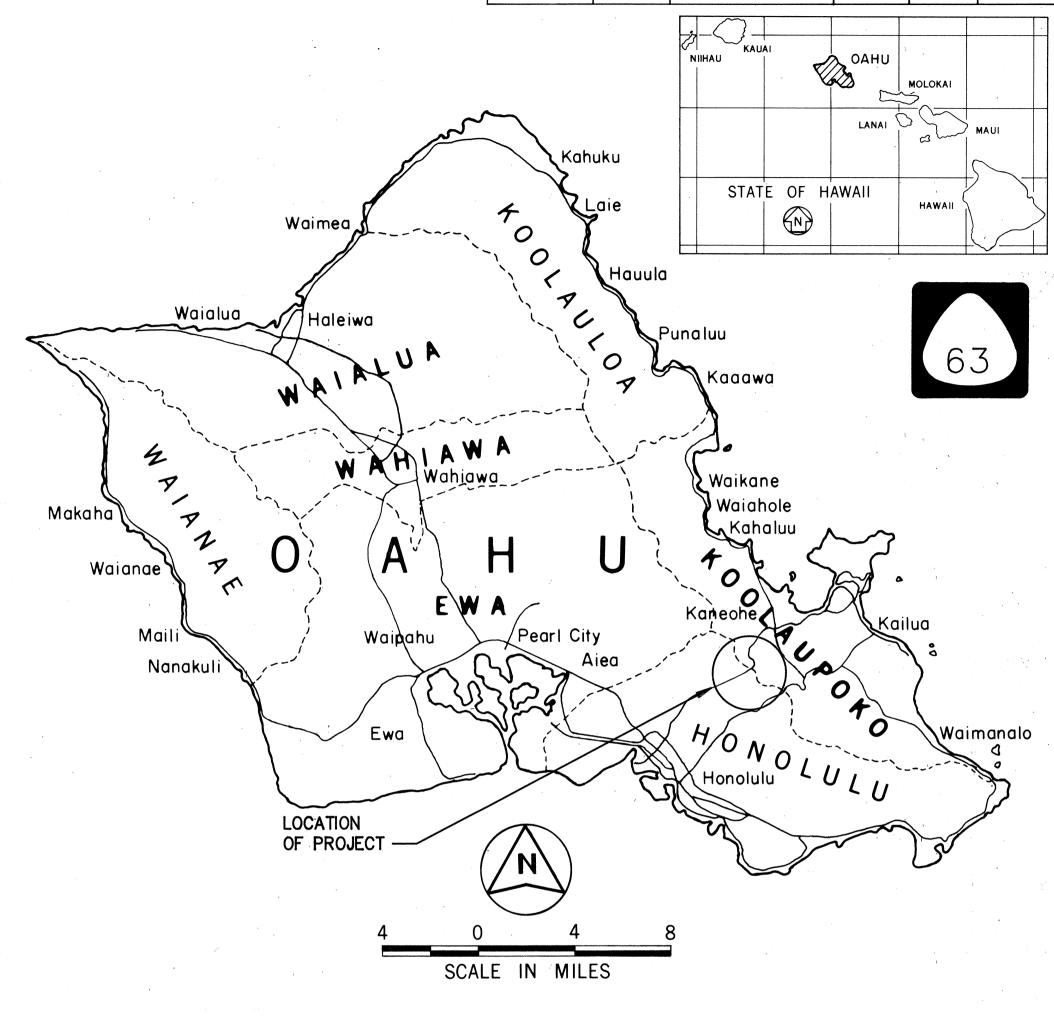

FED. ROAD DIST. NO.

FISCAL SHEET TOTAL YEAR NO. SHEETS

PROJ. NO.

63A-02-90

MILE POST 2.92 TO MILE POST 5.35

ALL CHANGES MADE DURING CONSTRUCTION HAVE BEEN NOTED IN RED ON THESE TRACINGS AND CHECKED BY Sidney 5. C. Tree 11/8/96 11/8/96 DATE

RESIDENT ENGINEER

DEPARTMENT OF TRANSPORTATION STATE OF HAWAII 11/8/91 DATE DIR. OF TRANSPORTATION