| | INDEX TO DRAWINGS |
|---|--|
| SHEET NO. | DESCRIPTION |
| | TITLE SHEET |
| | STANDARD PLANS SUMMARY |
| gradi de jarreja (n. 1907). La stati de propieta de la sectiona del sectiona de la sectiona de la sectiona del sectiona de la sectiona del | GENERAL PLAN & PROFILE |
| | TYPICAL ROADWAY SECTIONS |
| e a minima segue na gana manapatan da sa | FINAL STRIPING PLAN |
| 6 | GUARDRAIL AND POST DETAILS |
| 1 7-28 | BRIDGE PLANS AND DETAILS |
| 29-31 | TRAFFIC CONTROL PLANS |
| 32-33 | MECHANICAL PLAN, SECTIONS, AND DETAILS |
| 34-38 | ELECTRICAL PLANS AND DIAGRAMS |
| | |
| | |
| | |
| | |
| | |
| | |
| • | |
| | |
| | |
| | |

Plan Sht. Nos. CO12S-1, 20S-1 are supplementary sheet to this project.
TOTAL SHEET COUNT after "AS BUILT" postings.
40 Sheets.

STATE OF HAWAII

DEPARTMENT OF TRANSPORTATION


HIGHWAYS DIVISION
HONOLULU, HAWAII
"AS-BUILT"
PLANS FOR


SAND ISLAND BASCULE BRIDGE REHABILITATION PHASE II

FEDERAL AID PROJECT NO. BR-064-1(3)

DISTRICT OF HONOLULU

ISLAND OF OAHU

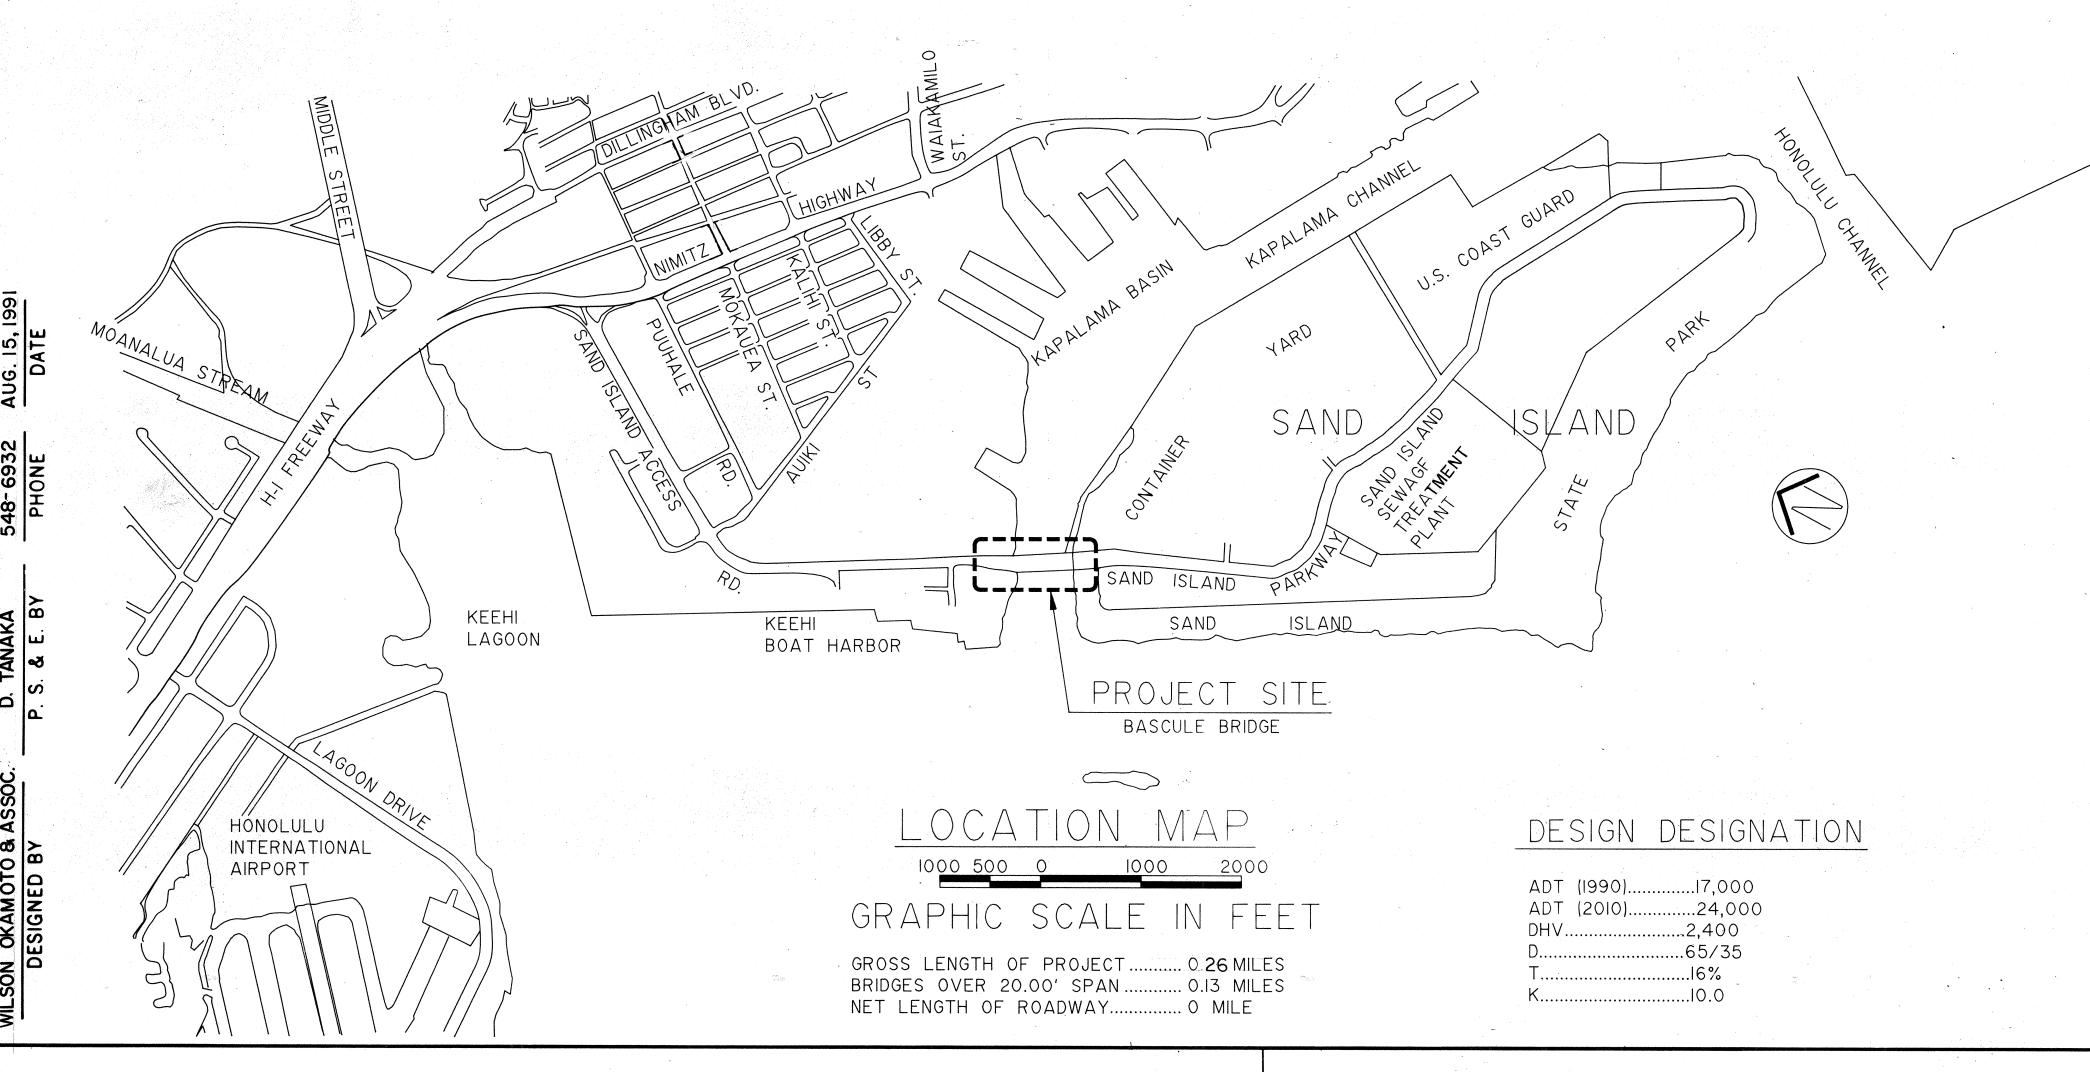

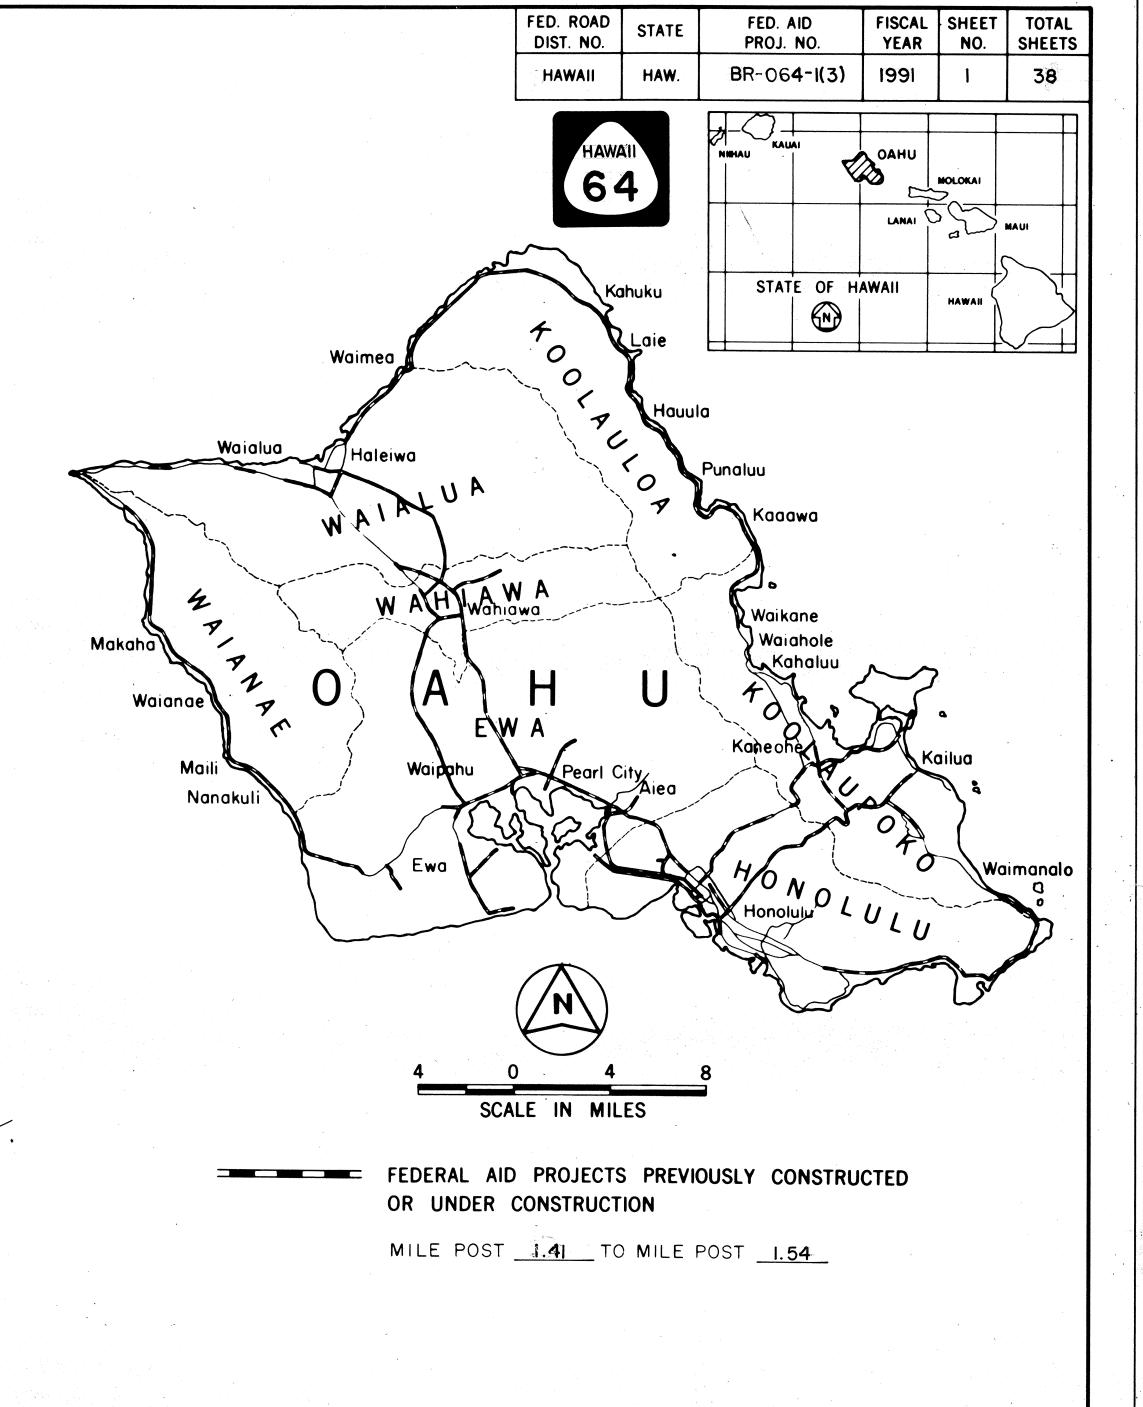

CHANGES MADE DURING CONSTRUCTION HAVE BEEN INCORPORATED ON THESE PLANS EXCEPT CHANGES IN THE ORIGINAL THEORETICAL QUANTITIES.

Sidney S. C. Ze 12/11/9
RESIDENT ENGINEER DATE

DEPARTMENT OF TRANSPORTATION
FEDERAL HIGHWAY ADMINISTRATION
APPROVED:

Machines 9/1/9/
ADIVISION ADMINISTRATOR DATE

DEPARTMENT OF TRANSPORTATION
STATE OF HAWAII

APPROVED:

Solution

Blue Solution

DIR. OF TRANSPORTATION

DATE