	· ·
INDEX TO DRAWINGS	
SHEET NO.	DESCRIPTION
	TITLE SHEET
2	PAVING, SIGNING & STRIPING PLAN
3-4	ELECTRICAL PLANS & DETAILS
5	POLE & ANCHORAGE DETAILS
6	PAVEMENT MARKING DETAILS
7-13	STANDARD DETAILS
	•
	,
, .	
,	-
İ	
	-,



STATE OF


DEPARTMENT TRANSPORTATION OF DIVISION HIGHWAYS

> HONOLULU, HAWAII "AS - BUILT" PLANS FOR


CONSTRUCTION OF A PORTION OF

FORT WEAVER ROAD TEMPORARY TRAFFIC SIGNALS AT RENTON ROAD PROJECT NO. 760A - 01 - 75

> DISTRICT OF EWA ISLAND OF OAHU

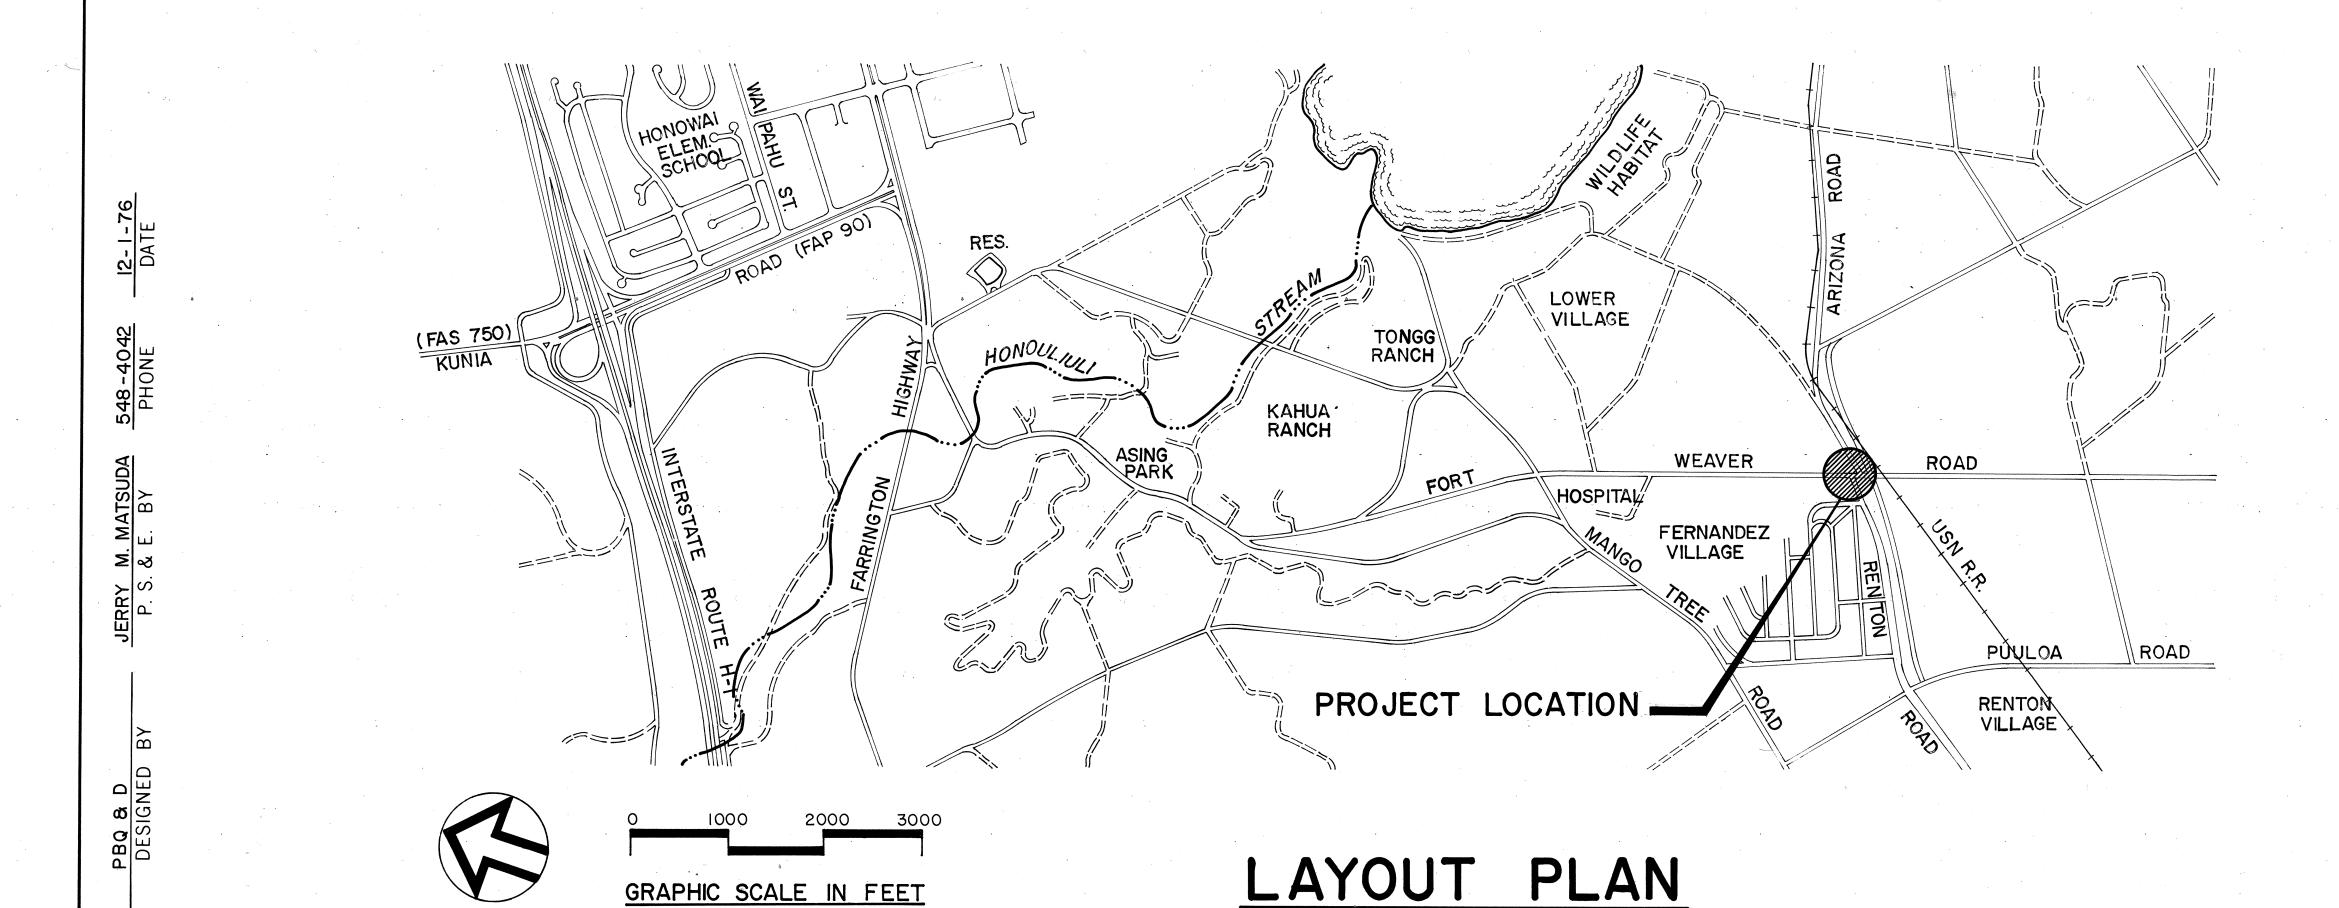

GRAPHIC SCALE IN FEET

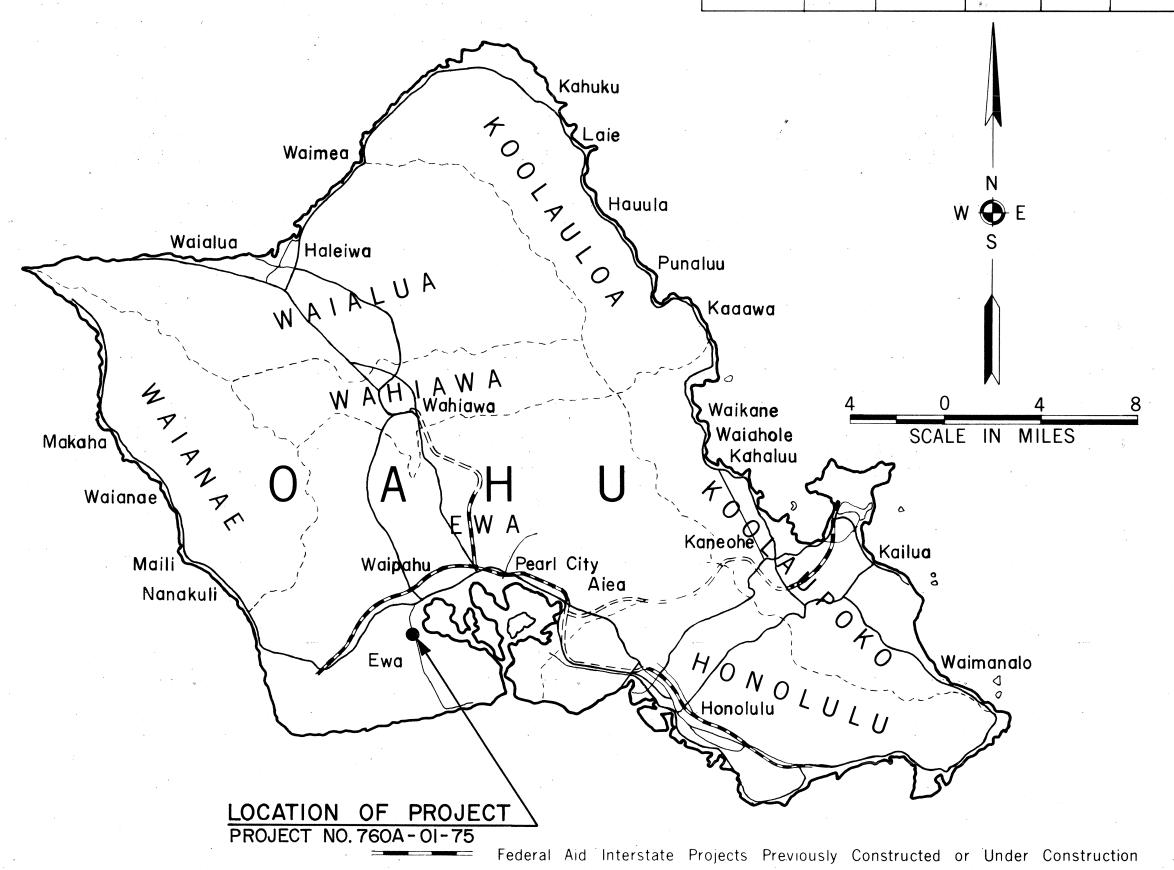

ALL CHANGES MADE DURING CONSTRUCTION HAVE BEEN INCORPORATED ON THESE PLANS IN RED EXCEPT CHANGES IN THE ORIGINAL THEORETICAL QUANTITIES. FOR ACTUAL QUANTITIES, REFER TO PROJECT LEDGER AND/OR COMPUTATION BOOK.

Phil aleneastre RESIDENT ENGINEER 11-19-80 DATE

DEPARTMENT OF TRANSPORTATION STATE OF HAWAII