

GENERAL UTILITY NOTES

- 1. The Contractor shall be liable for damage to any existing utility and structure.
- 2. The existence and location of underground utilities, appurtenances and structures as shown on the Plans are based on existing records of varying degrees of accuracy and completeness. They are not guaranteed as to the location shown or that other obstacles may not be encountered in the course of work. The Contractor shall assume that existing utilities may exist, although not shown.
- 3. Restoration of existing improvements unavoidably demolished due to work on utility reconstructions shall be incidental to the various contract items. Restoration shall be to original or better condition.
- 4. The Contractor shall give all property owners five (5) days notice before entering into their respective properties
- 5. Roadway construction work from FWR Sta. 160+00 to Sta. 204+50 to be built in future contract, except for utilities relocation works indicated.

BOARD OF WATER SUPPLY NOTES

- 1. Unless otherwise specified, all materials and construction of the water system facilities and appurtenances shall be in accordance with the Standard Specifications for Road and Bridge Construction, dated 1976, and as amended, of the Hawaii Highways Division, Department of Transportation.
- 2. The Contractor shall give the Board of Water Supply in writing, at least one-week advance notice of intent to commence work on the water system.
- 3. Prior to excavating for other new utility lines, the Contractor shall verify in the field the location of existing water mains and appurtenances. Where other new utility lines are to cross over or under existing water mains, the Contractor shall expose the existing water mains prior to trenching. Excavation around water mains shall be done by hand.
- 4. Unless otherwise specified, ductile iron pipe Class 52 shall be used for reconstructed 6-inch water lines with test pressure of 150 psi.
- 5. All shown information for connection to existing water lines shall be verified in the field by the Contractor and shall be adjusted as necessary.
- 6. There shall be a minimum horizontal clearance of 3 feet, and a minimum vertical clearance of 6 inches, between water mains and other utilities.
- 7. Unless otherwise specified, connections to existing water mains & chlorination of new mains shall be done by the Contractor, with the BWS inspector coordinating the work. For details, contact BWS Engineering Division, Construction Section.
- 8. Plans approved by the Board of Water Supply are based solely on the adequacy of the water supply. Discrepancies if any, of alignments, grades, fittings, etc., are not the responsibility of the Board of Water Supply.
- 9. All Cast Iron (Gray or Ductile) Water Mains, fittings & valves shall be enclosed in plastic material in accordance with ANSI Specifications A21.5-1972 or AWWA Specifications C105-72 "Polyethylene Encasement for Gray & Ductile Cast Iron Piping for Water and Other Liquids".
- 10. Reapproval shall be required if this project is not under construction within a period of one year from Date on signature block. See Rules and Regulations of the Board of Water Supply.

TELEPHONE NOTES
(HAWAIIAN TELEPHONE CO.,)

- 1. The Contractor shall give HTCo, in writing, at least 20 working days advance notice of intent to commence work on the telephone system.
- 2. Existing telephone facilities shown on these plans are approximate only. The Contractor shall verify their actual location and shall make adjustments to the proposed facility as directed by HTCo.
- 3. HTCo. will coordinate its work with the Contractor in such a manner as to expedite construction.
- 4. All exist. poles, anchors, & cables owned or erected by HTCo. will be removed by HTCo.
- 5. The Contractor shall provide HTCo. with 48 hours notice for toning and marking of existing HTCo. or Military underground facilities prior to excavating in Project Area.
- 6. All exist. HTCo. and Military cable facilities shall remain in place until the proposed facilities are installed.

ELECTRIC NOTES
(HAWAIIAN ELECTRIC CO., INC.)

- 1. All existing facilities shall remain in place until the proposed facilities are installed. Existing electric facilities shown on these plans are approximate only. The Contractor shall verify their actual locations and shall make adjustments to the proposed facility as directed by HECO.
- 2. HECO. will coordinate its work with the Contractor in such a manner as to expedite construction.
- 3. All materials required for the location and rearrangement of the HECO's overhead facilities will be furnished by HECO.
- 4. Excavation of pole holes and anchors, Installation & Removal of poles & anchors, and backfill of pole holes and anchors will be done by HECO. Stake out of wood pole and anchor locations to be done by HECO.
- 5. State and/or its Contractor to stake out R/W, Base Line, Stations and Cuts and/or Fills.
- 6. State and/or its Contractor to assist HECO. in the staking out of Proposed Poles.

BOARD OF WATER SUPPLY NOTES (CONTINUED)

- 11. Any adjustments to the existing water system required during construction to meet requirements of BWS standards, whether shown on the plans or not, shall be done by the Contractor at no cost to the Board of Water Supply.

DATE	REVISION	FED. ROAD DIST. NO.	STATE	FED. AID PROJ. NO.	FISCAL YEAR	SHEET NO.	TOTAL SHEETS
6/23/81	Revised BWS Note 8. Added BWS Note 11. Added BWS Reapproval Block.	HAWAII	HAW.	M-7600 (2)	1980	133	244

LEGEND FOR UTILITY DRAWINGS

New Facilities.....	_____
Existing Facilities to remain.....	_____
Existing Facilities to be : Removed, demolished, abandoned or relocated when new lines are in service.....	+++++++
Telephone - Underground (HTCo.).....	—Tu—
Telephone - Aerial (HTCo.).....	—TA—
Electric - Aerial (HECo.).....	—EA—
Army Communications Cable.....	—ACC—
Water (BWS).....	—W16"—
Water (Oahu Sugar Co.).....	—W6"(O)—
Sewer (Oahu Sugar Co.).....	—S6"(O)—
Water (U.S.Navy).....	—W12"(USN)—
Abandoned Gas (U.S.Navy).....	—G8"(USN)—
Oil Line (Standard Oil Co.).....	—OIL 8"—
New Anchor Pole.....	➤
Water Valve Box.....	WV
Manhole.....	MH
Traffic Signal - Aerial.....	TSa
New Joint Pole.....	⊙ J.P.

ELECTRIC NOTES (CONTINUED)

- 7. Contact HECO. Underground Division at 548-7395 a minimum of seventy-two (72) hours in advance for verifying the location of underground duct lines and for assistance in providing for support and protection of underground duct lines.
- 8. Contact HECO District Construction Superintendent Mr. Walter Okudara at 455-2933 a minimum of seventy-two (72) hours in advance for assistance in providing pole bracing instructions should field conditions and/or construction procedures require that poles be braced to facilitate construction.

REAPPROVAL:

R. Hagata 7-9-81
for Chief, Planning & Engineering, BWS Date

R. Hagata 3-6-79
for Chief, Planning & Engineering, BWS Date

W. C. Loo 10/24/79
Hawaiian Electric Co., Inc. Date

P. Yamada 11-8-79
Hawaiian Telephone Co. Date

STATE OF HAWAII
DEPARTMENT OF TRANSPORTATION
HIGHWAYS DIVISION

GENERAL UTILITY NOTES
AND LEGEND






FORT WEAVER ROAD
SOUTH OF FARRINGTON HIGHWAY
TO THE VICINITY OF RENTON ROAD
DATE: SEPT 1979

SHEET NO. 1 OF 1 SHEETS

FED. ROAD DIST. NO.	STATE	FED. AID PROJ. NO.	FISCAL YEAR	SHEET NO.	TOTAL SHEETS
HAWAII	HAW.	M-7600 (2)	1980	134	244

HO'AE'AE' WATER MAIN NOTES

1. Unless otherwise specified, all materials and construction of the water system facilities and appurtenances shall be in accordance with the Standard Specifications for Road and Bridge Construction, dated 1976, and as amended, of the Hawaii Highways Division, Department of Transportation.
2. The Contractor shall notify the Engineer in writing at least 7 days prior to the time that the Contractor performs the connections to the existing water main.
3. All shown information for connection to existing water line shall be verified in the field by the Contractor and shall be adjusted as necessary.
4. Unless otherwise specified, chlorination of relocated main shall be done by the Contractor.

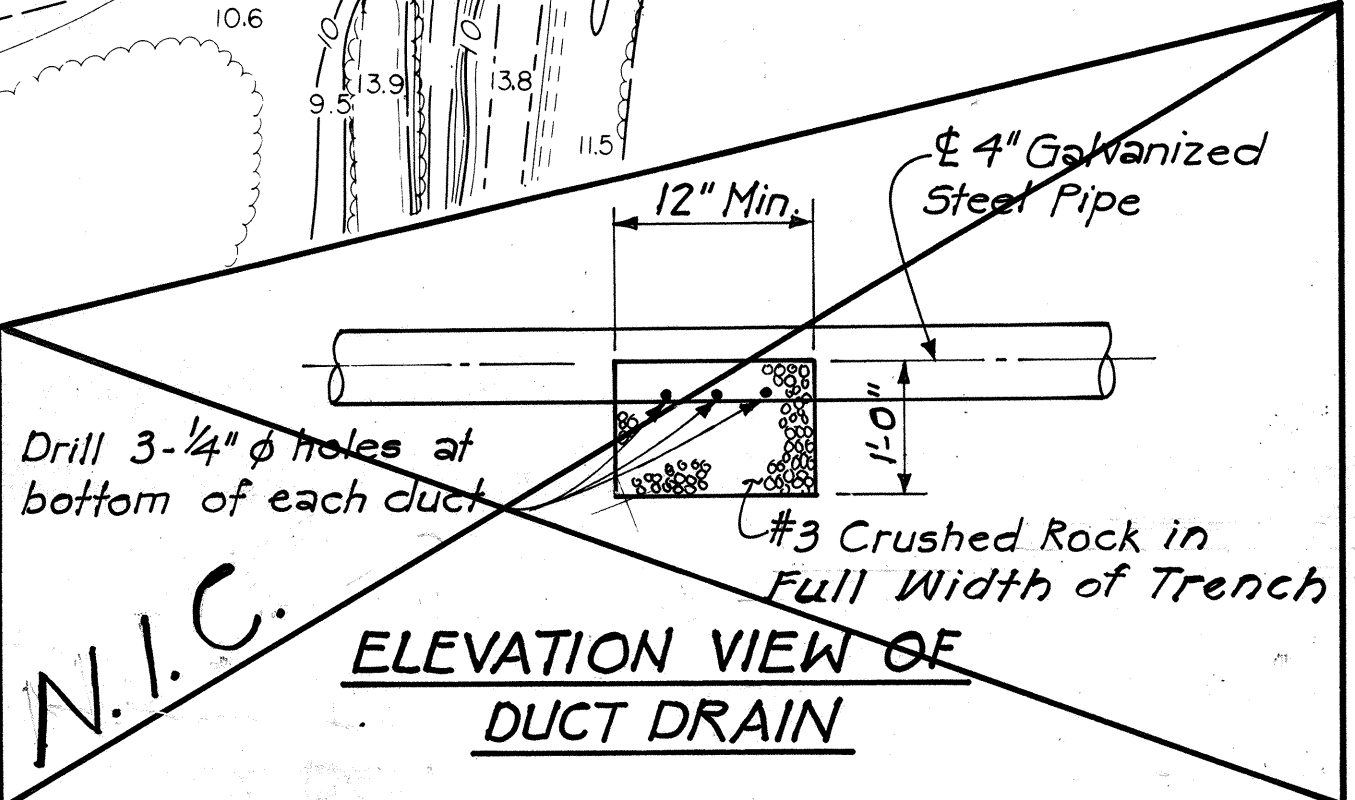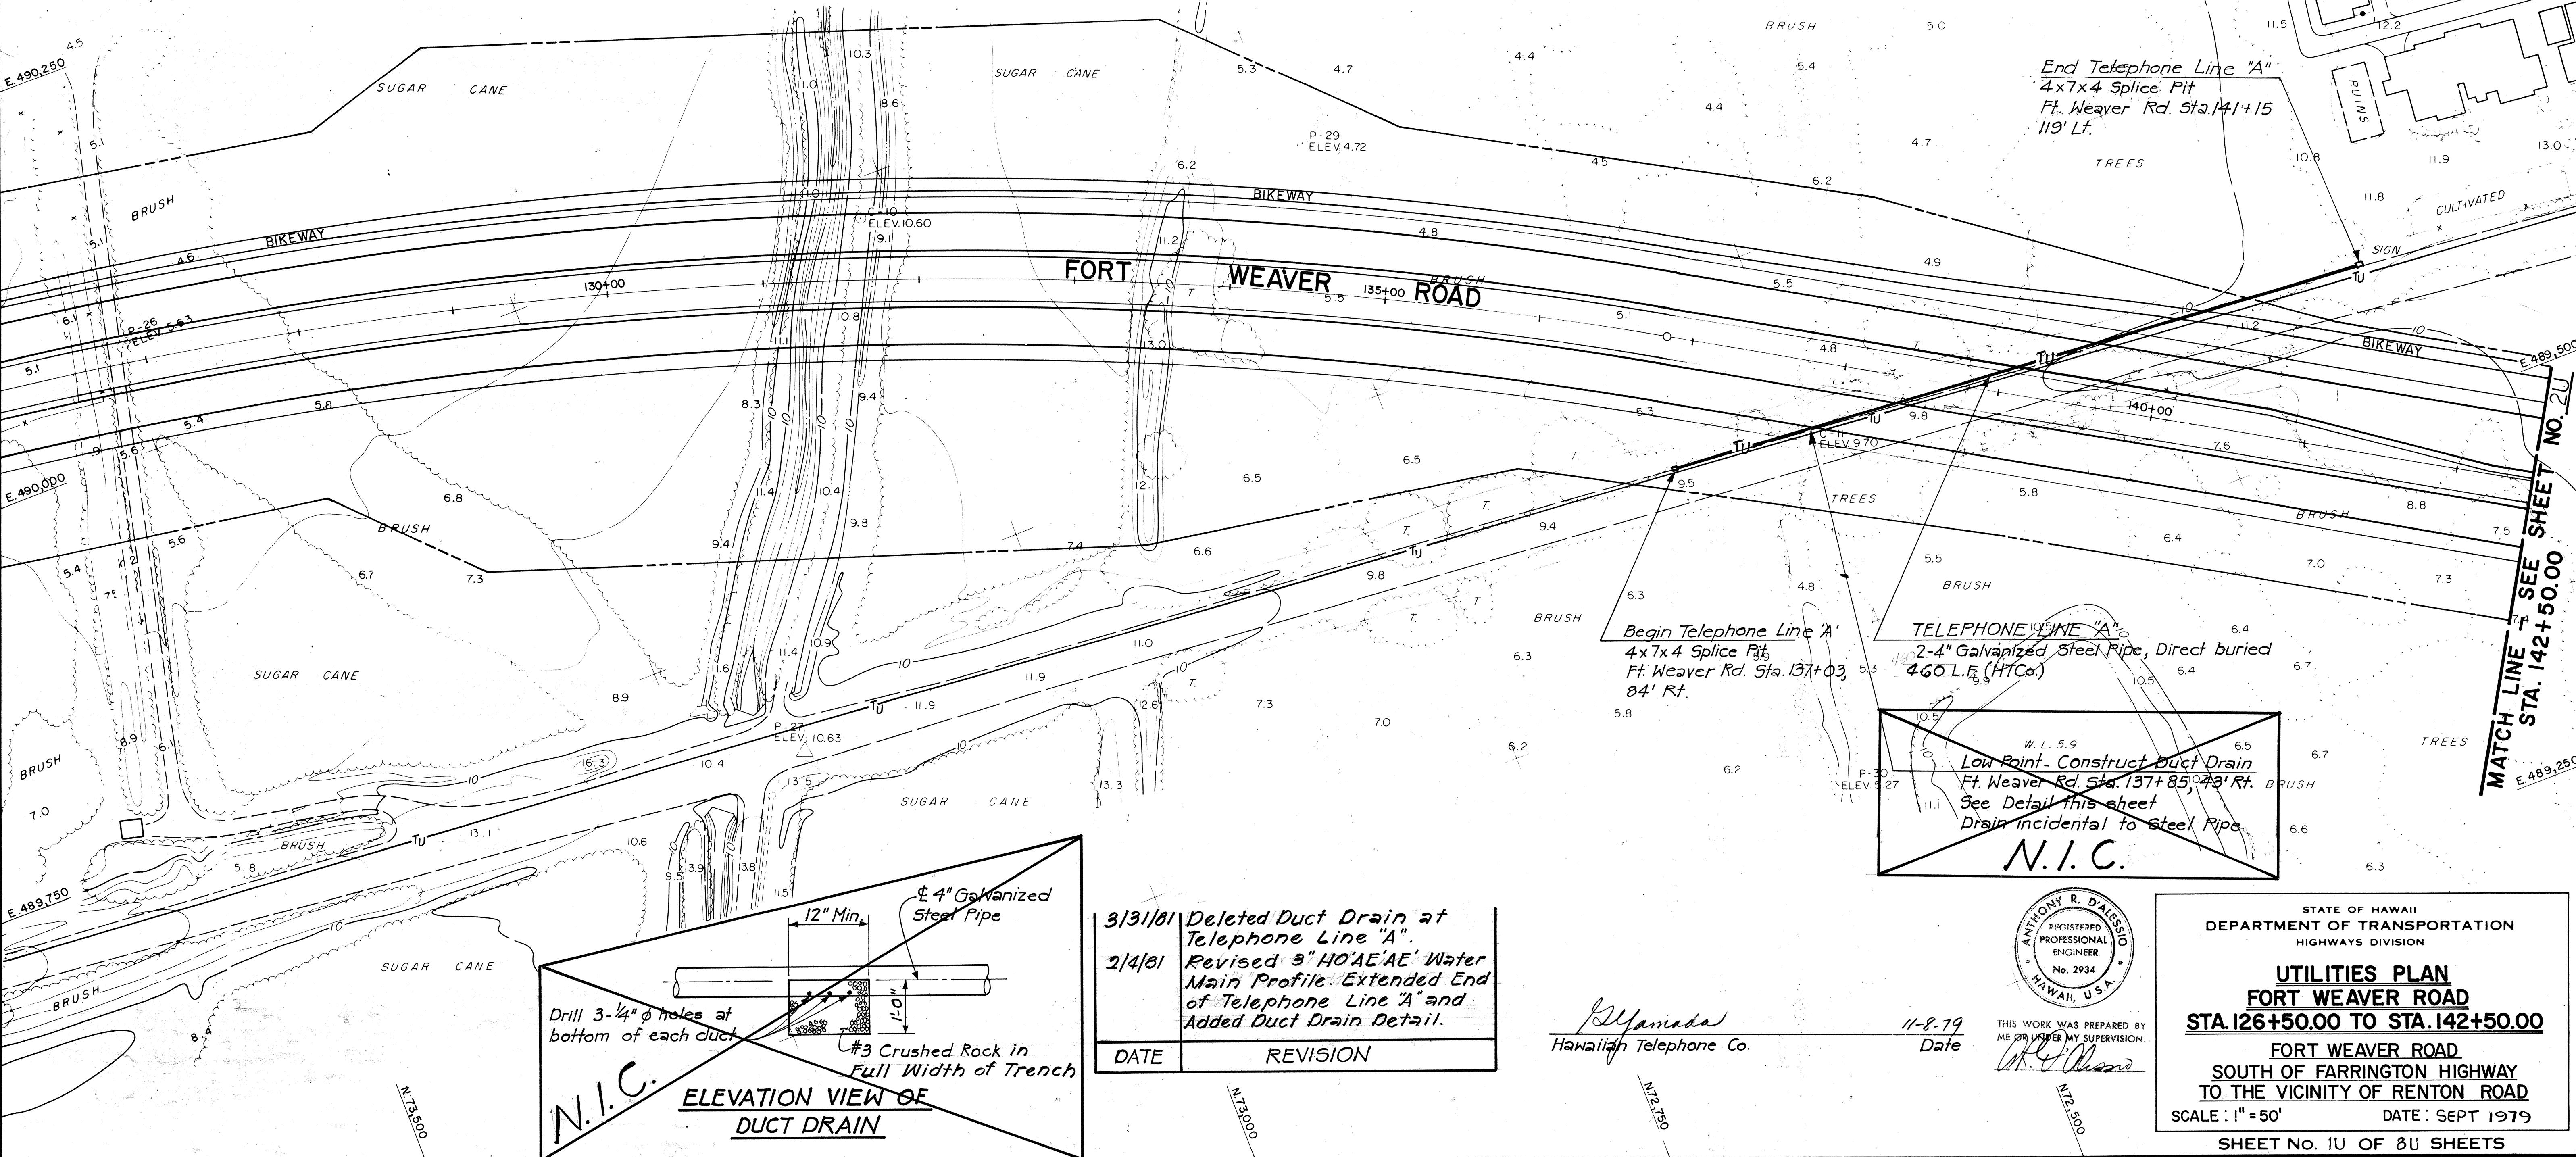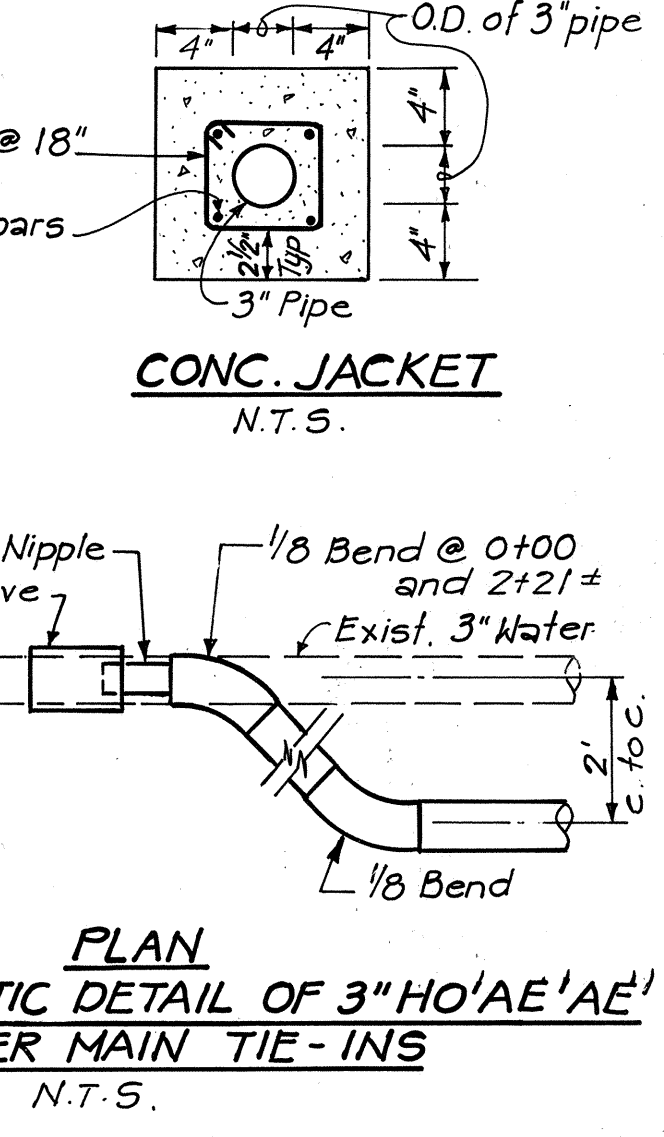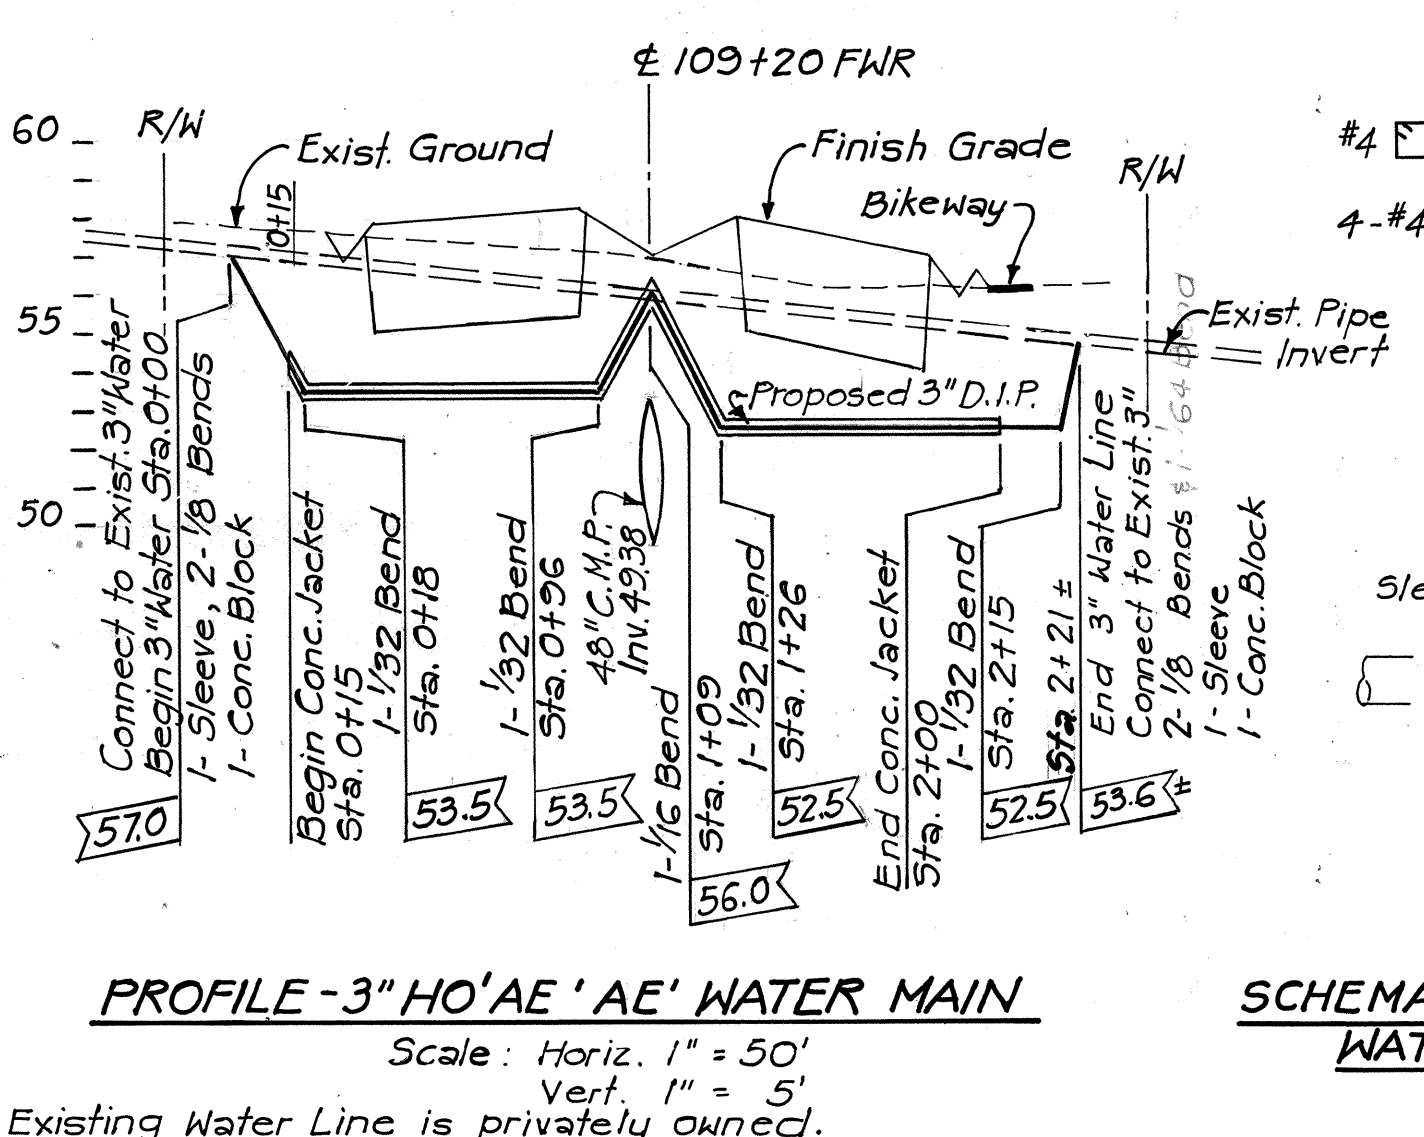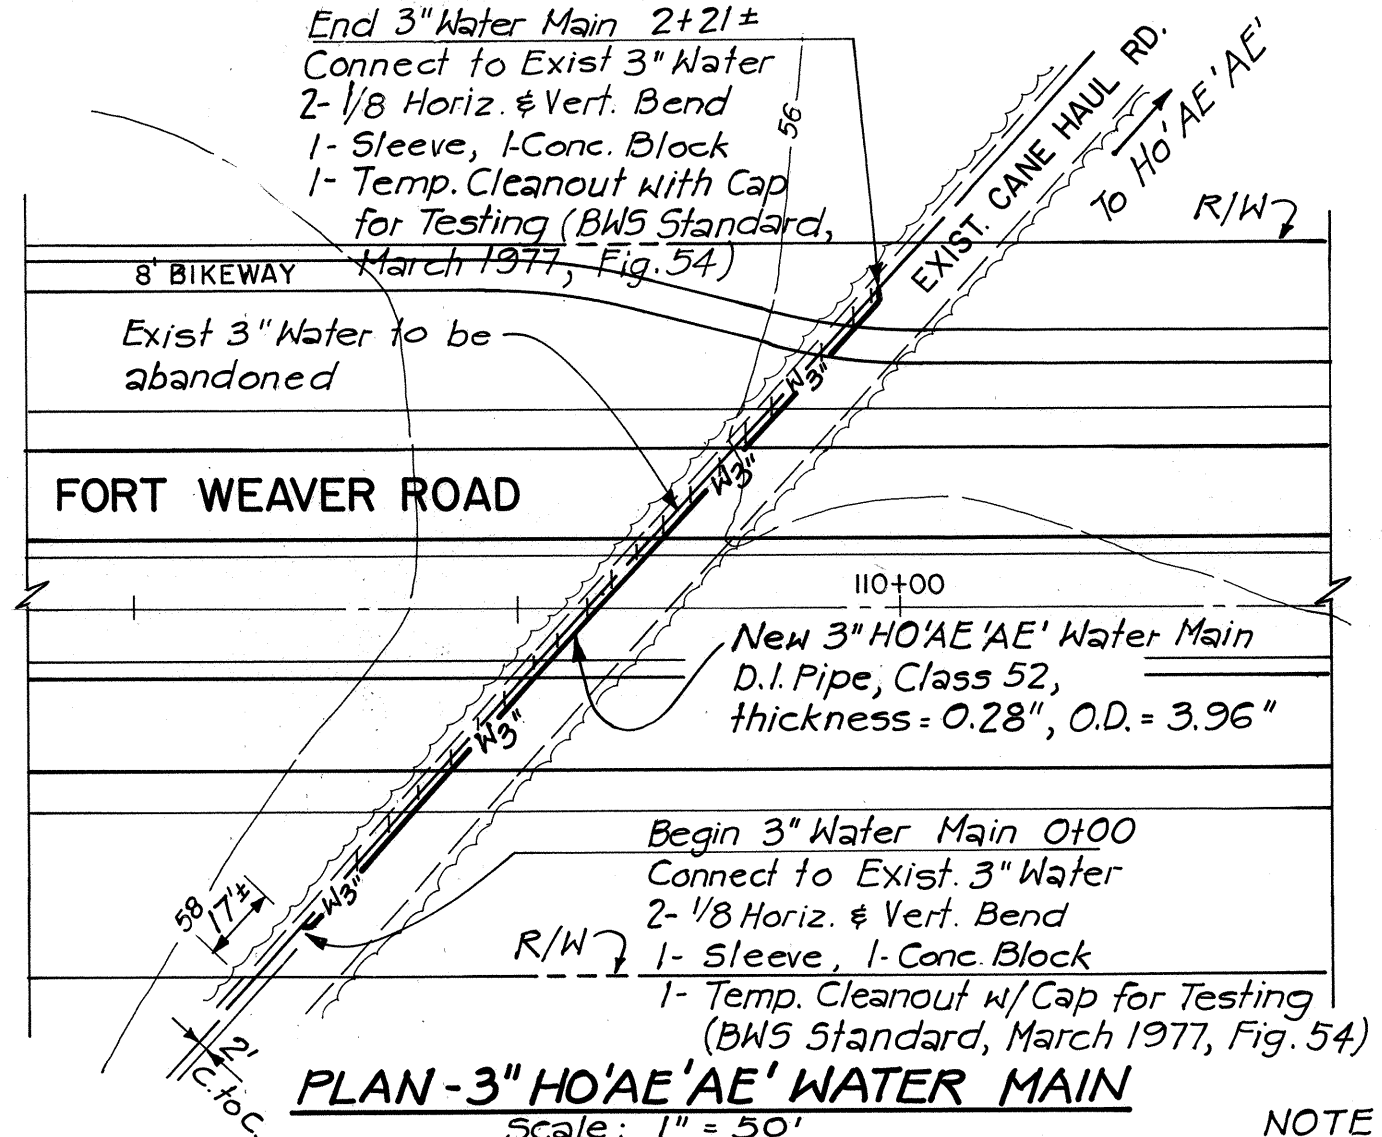

DATE	REVISION
3/31/81	Deleted Duct Drain at Telephone Line "A".
2/4/81	Revised 3" HO'AE'AE' Water Main Profile. Extended End of Telephone Line "A" and Added Duct Drain Detail.




STATE OF HAWAII
DEPARTMENT OF TRANSPORTATION
HIGHWAYS DIVISION


UTILITIES PLAN
FORT WEAVER ROAD
STA. 126+50.00 TO STA. 142+50.00
FORT WEAVER ROAD
SOUTH OF FARRINGTON HIGHWAY
TO THE VICINITY OF RENTON ROAD
SCALE: 1" = 50' DATE: SEPT 1979
SHEET NO. 10 OF 80 SHEETS

DATE	____
SURVEY PLOTTED BY	____
DRAWN BY	____
DESIGNED BY	____
CHECKED BY	____
NOTE BOOK	____
NO.	____

FED. ROAD DIST. NO.	STATE	FED. AID PROJ. NO.	FISCAL YEAR	SHEET NO.	TOTAL SHEETS
HAWAII	HAW.	M-7600(2)	1981	C01355-1	244

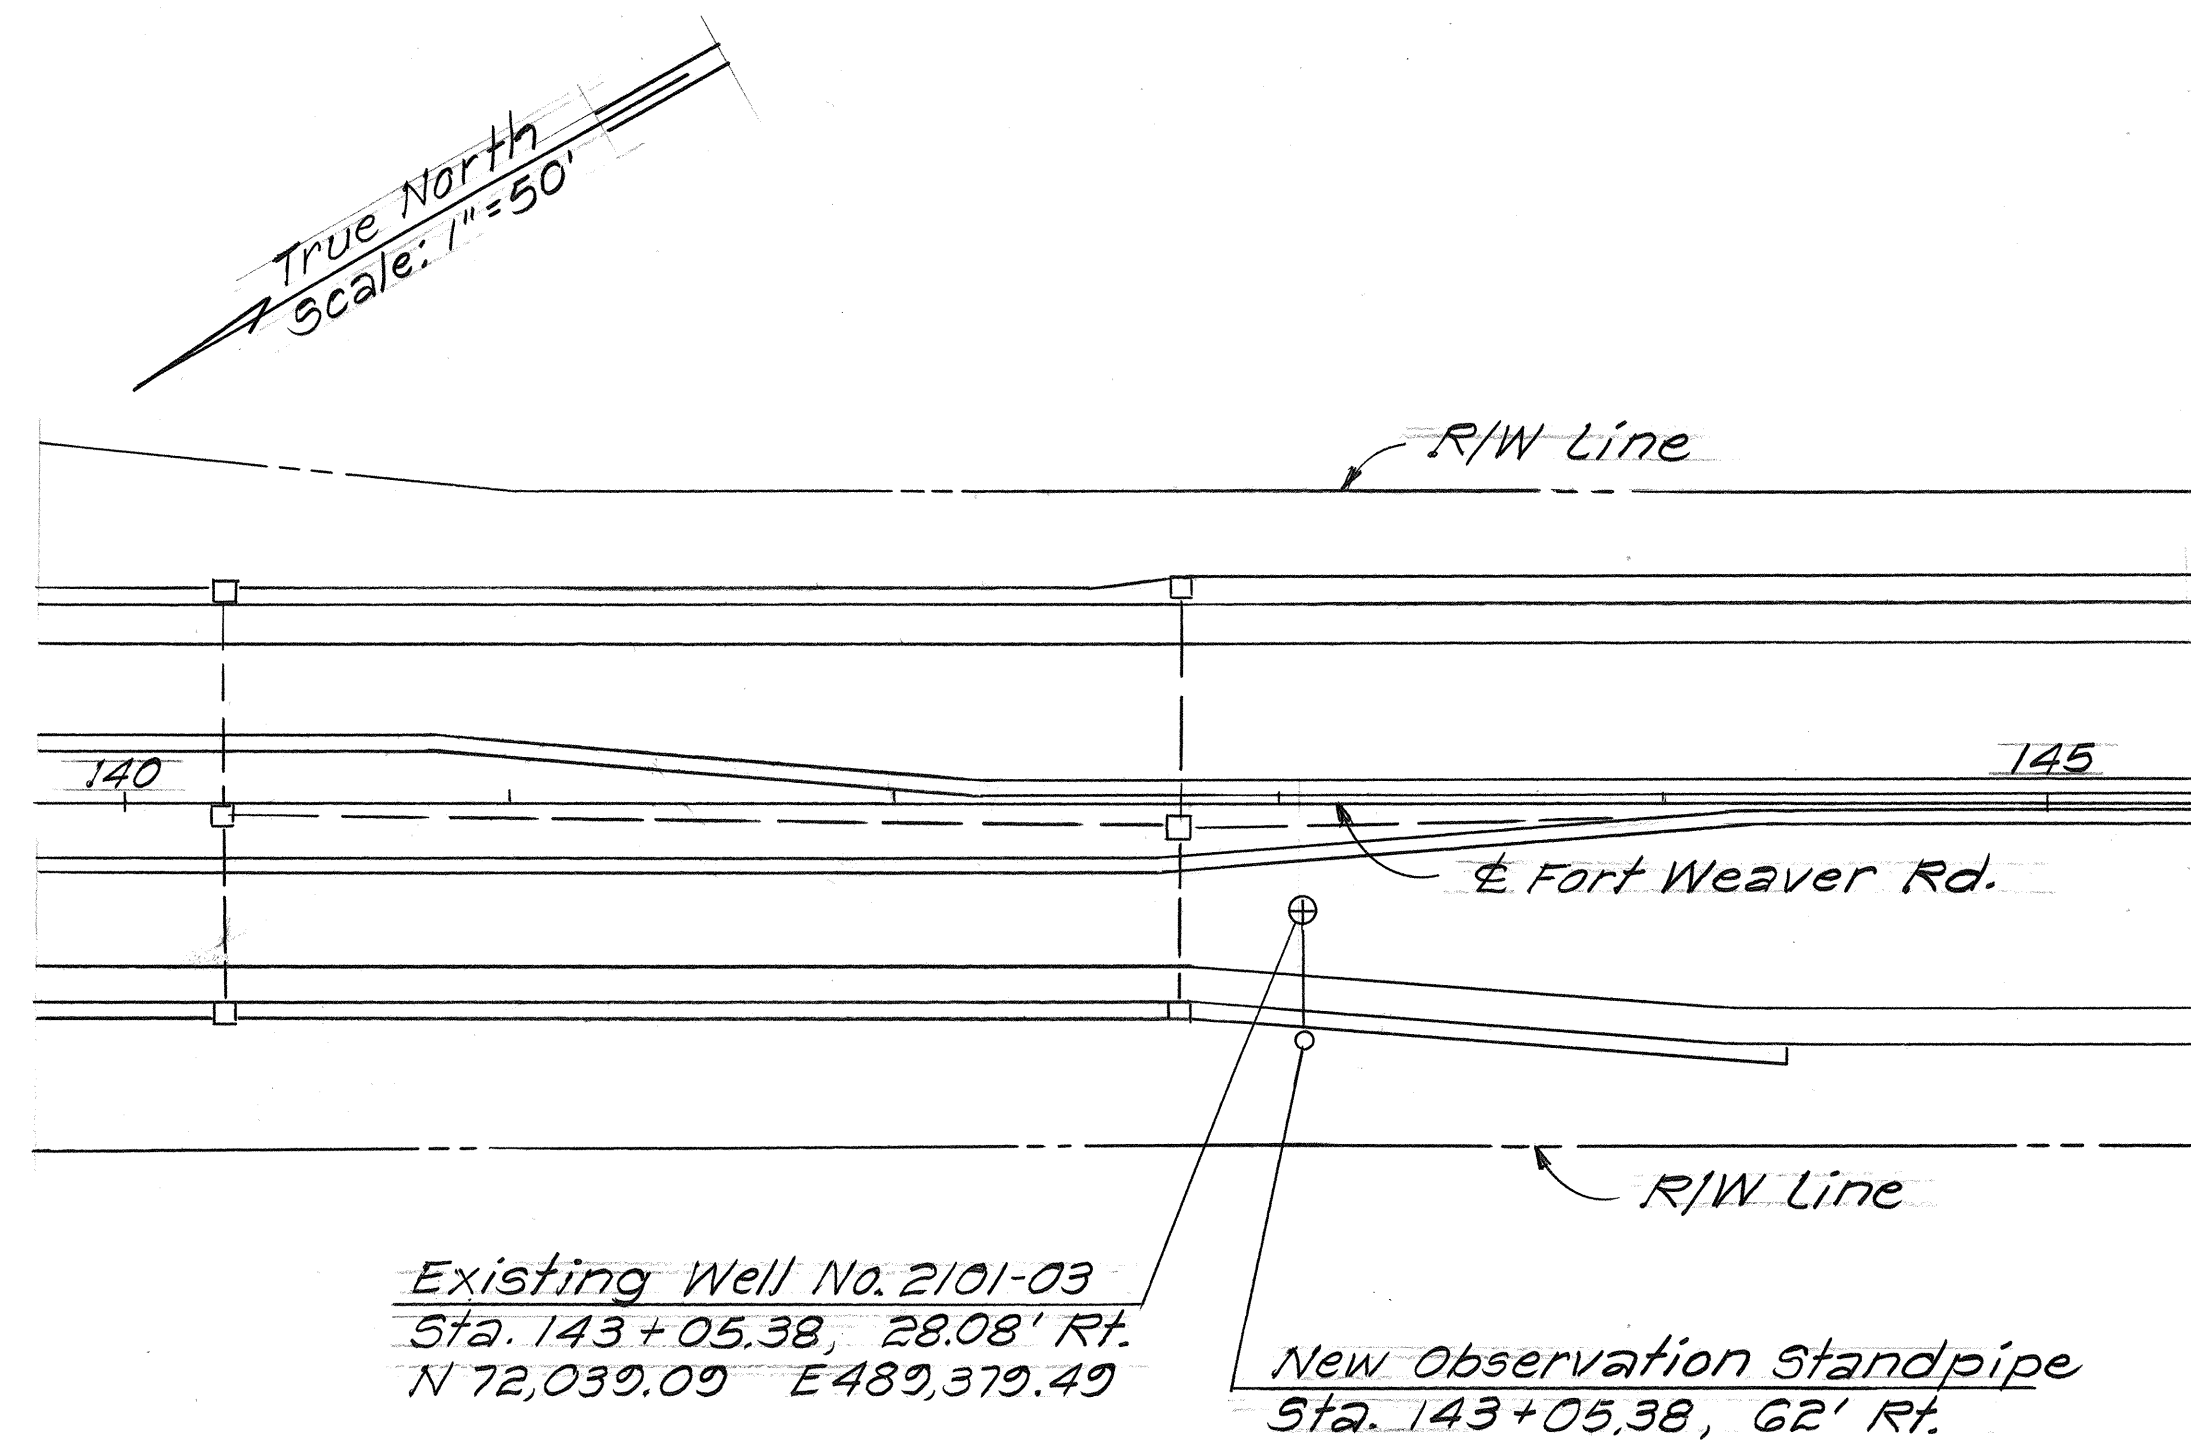


PLAN
Scale: 1" = 50'

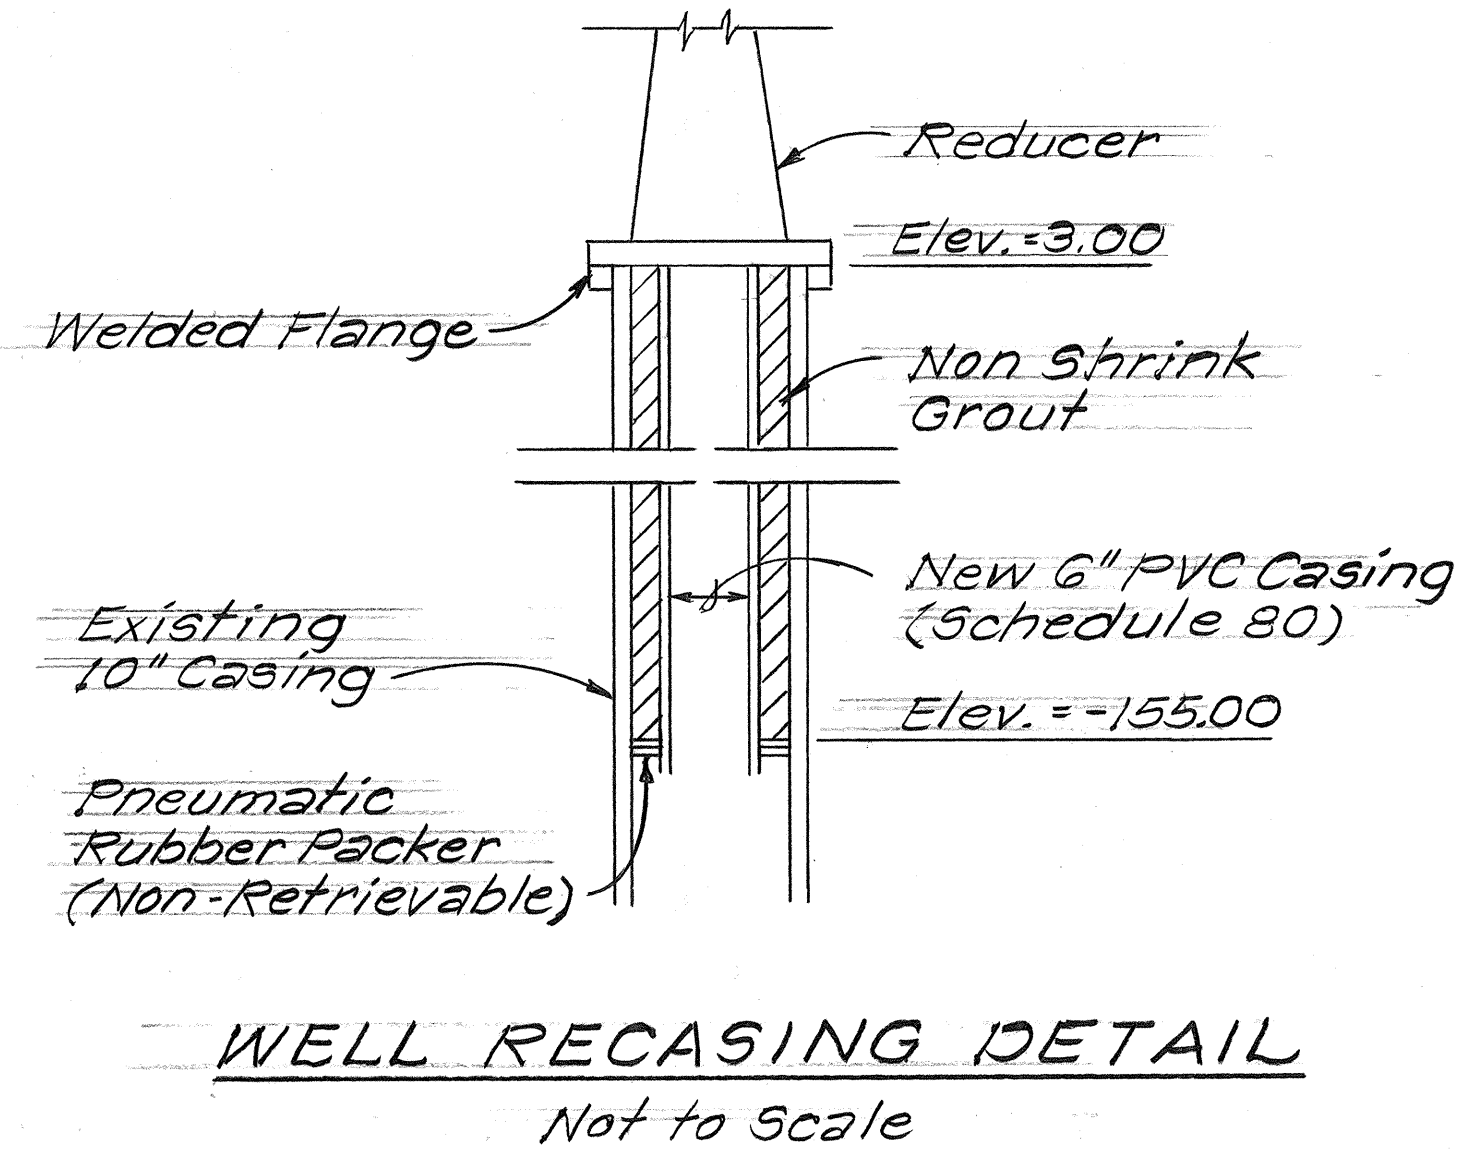

NOTES:

1. The Type P Cast Iron Frames and Covers shall bear the inscription "Observation Well" See details on Sheet No. 50.
2. Before commencing work on the well, the Contractor shall notify the U.S. Geological Survey, Water Resources Division (Benjamin L. Jones, District Chief) at 546-8331.
3. The Contractor shall also provide two days advance notification to the Department of Land and Natural Resources, Division of Water and Land Development (Robert T. Chuck, Manager-Chief Engineer) at 548-7533.
4. Remove existing 10" Well Casing to Elev. 3.00 and install flange. Clean existing casing and install new 6" PVC casing to Elev. -155. Fill annulus with non-shrink grout. See Well Recasing Detail this sheet.
5. Provide 2" minimum space between manhole wall and upper half of barrel of pipe. Fill with asphalt filler.
6. Water proof outside of Type A Manhole below Elev. 10 per Subsection 503.03(H) of Standard Specifications.

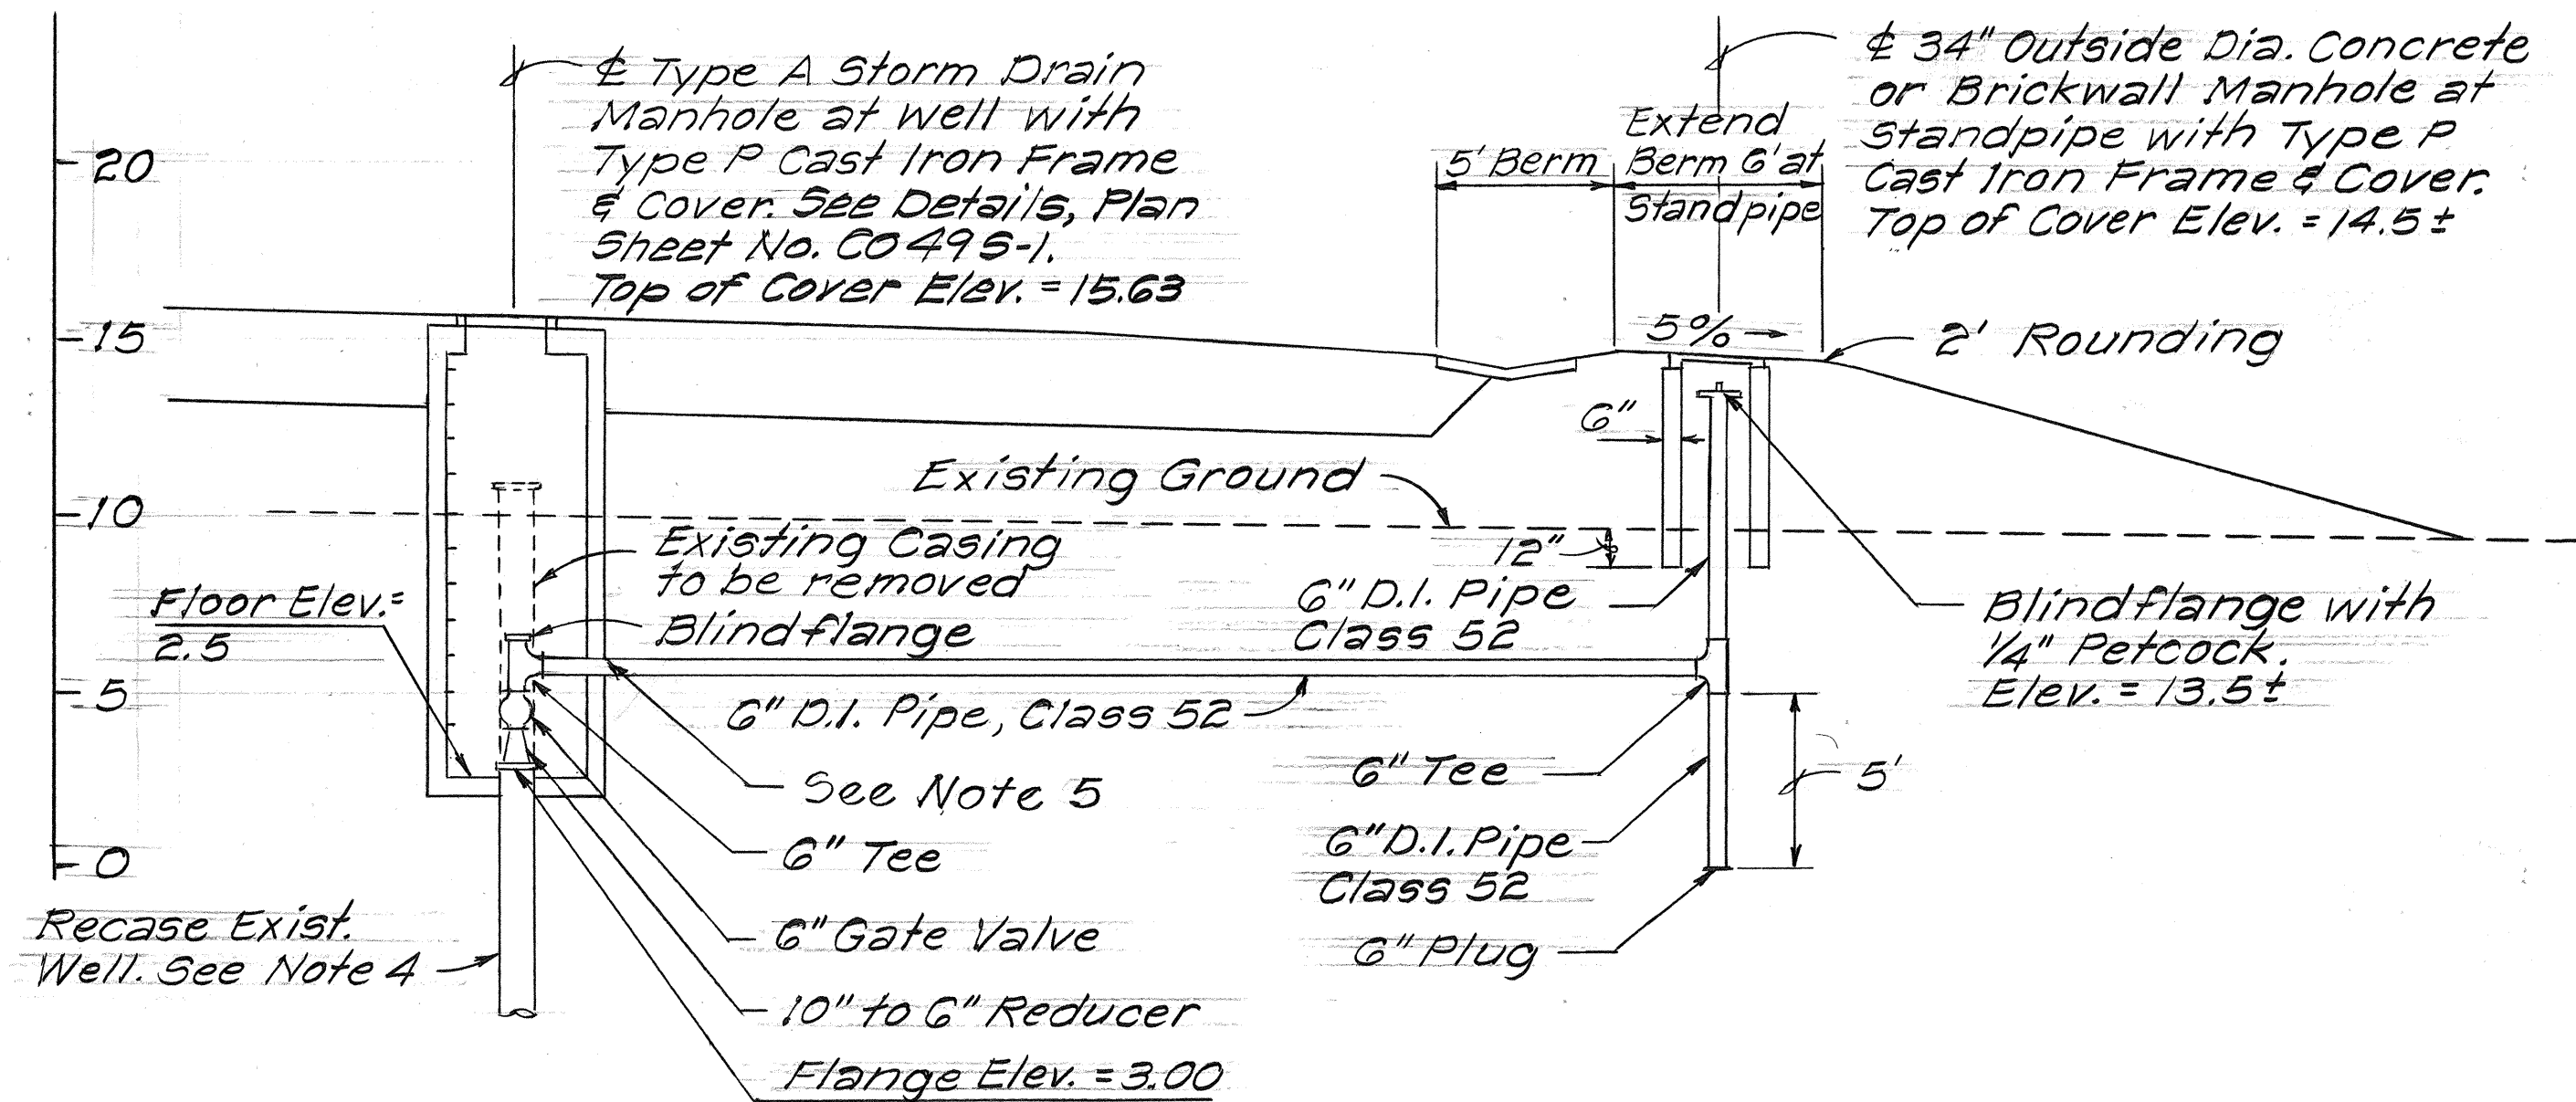

SECTION
Scale: 1" = 5'

STATE OF HAWAII
DEPARTMENT OF TRANSPORTATION
LAND TRANSPORTATION FACILITIES DIVISION

WELL NO. 2101-03
CONVERSION TO OBSERVATION WELL

FORT WEAVER ROAD
SOUTH OF FARRINGTON HIGHWAY
TO THE VICINITY OF RENTON ROAD

Scale: As Shown Date: Jan. 1981

SHEET No. 244 OF 80 SHEETS

C01355-1

FED. ROAD DIST. NO.	STATE	FED. AID PROJ. NO.	FISCAL YEAR	SHEET NO.	TOTAL SHEETS
HAWAII	HAW.	M-7600 (2)	1980	136	244

N 71,000

E 488,750

N 72,250

N 72,000

N 71,750

N 71,500

N 71,250

E 488,500


E 488,250

E 488,000


E 488,750

E 488,500

E 488,250

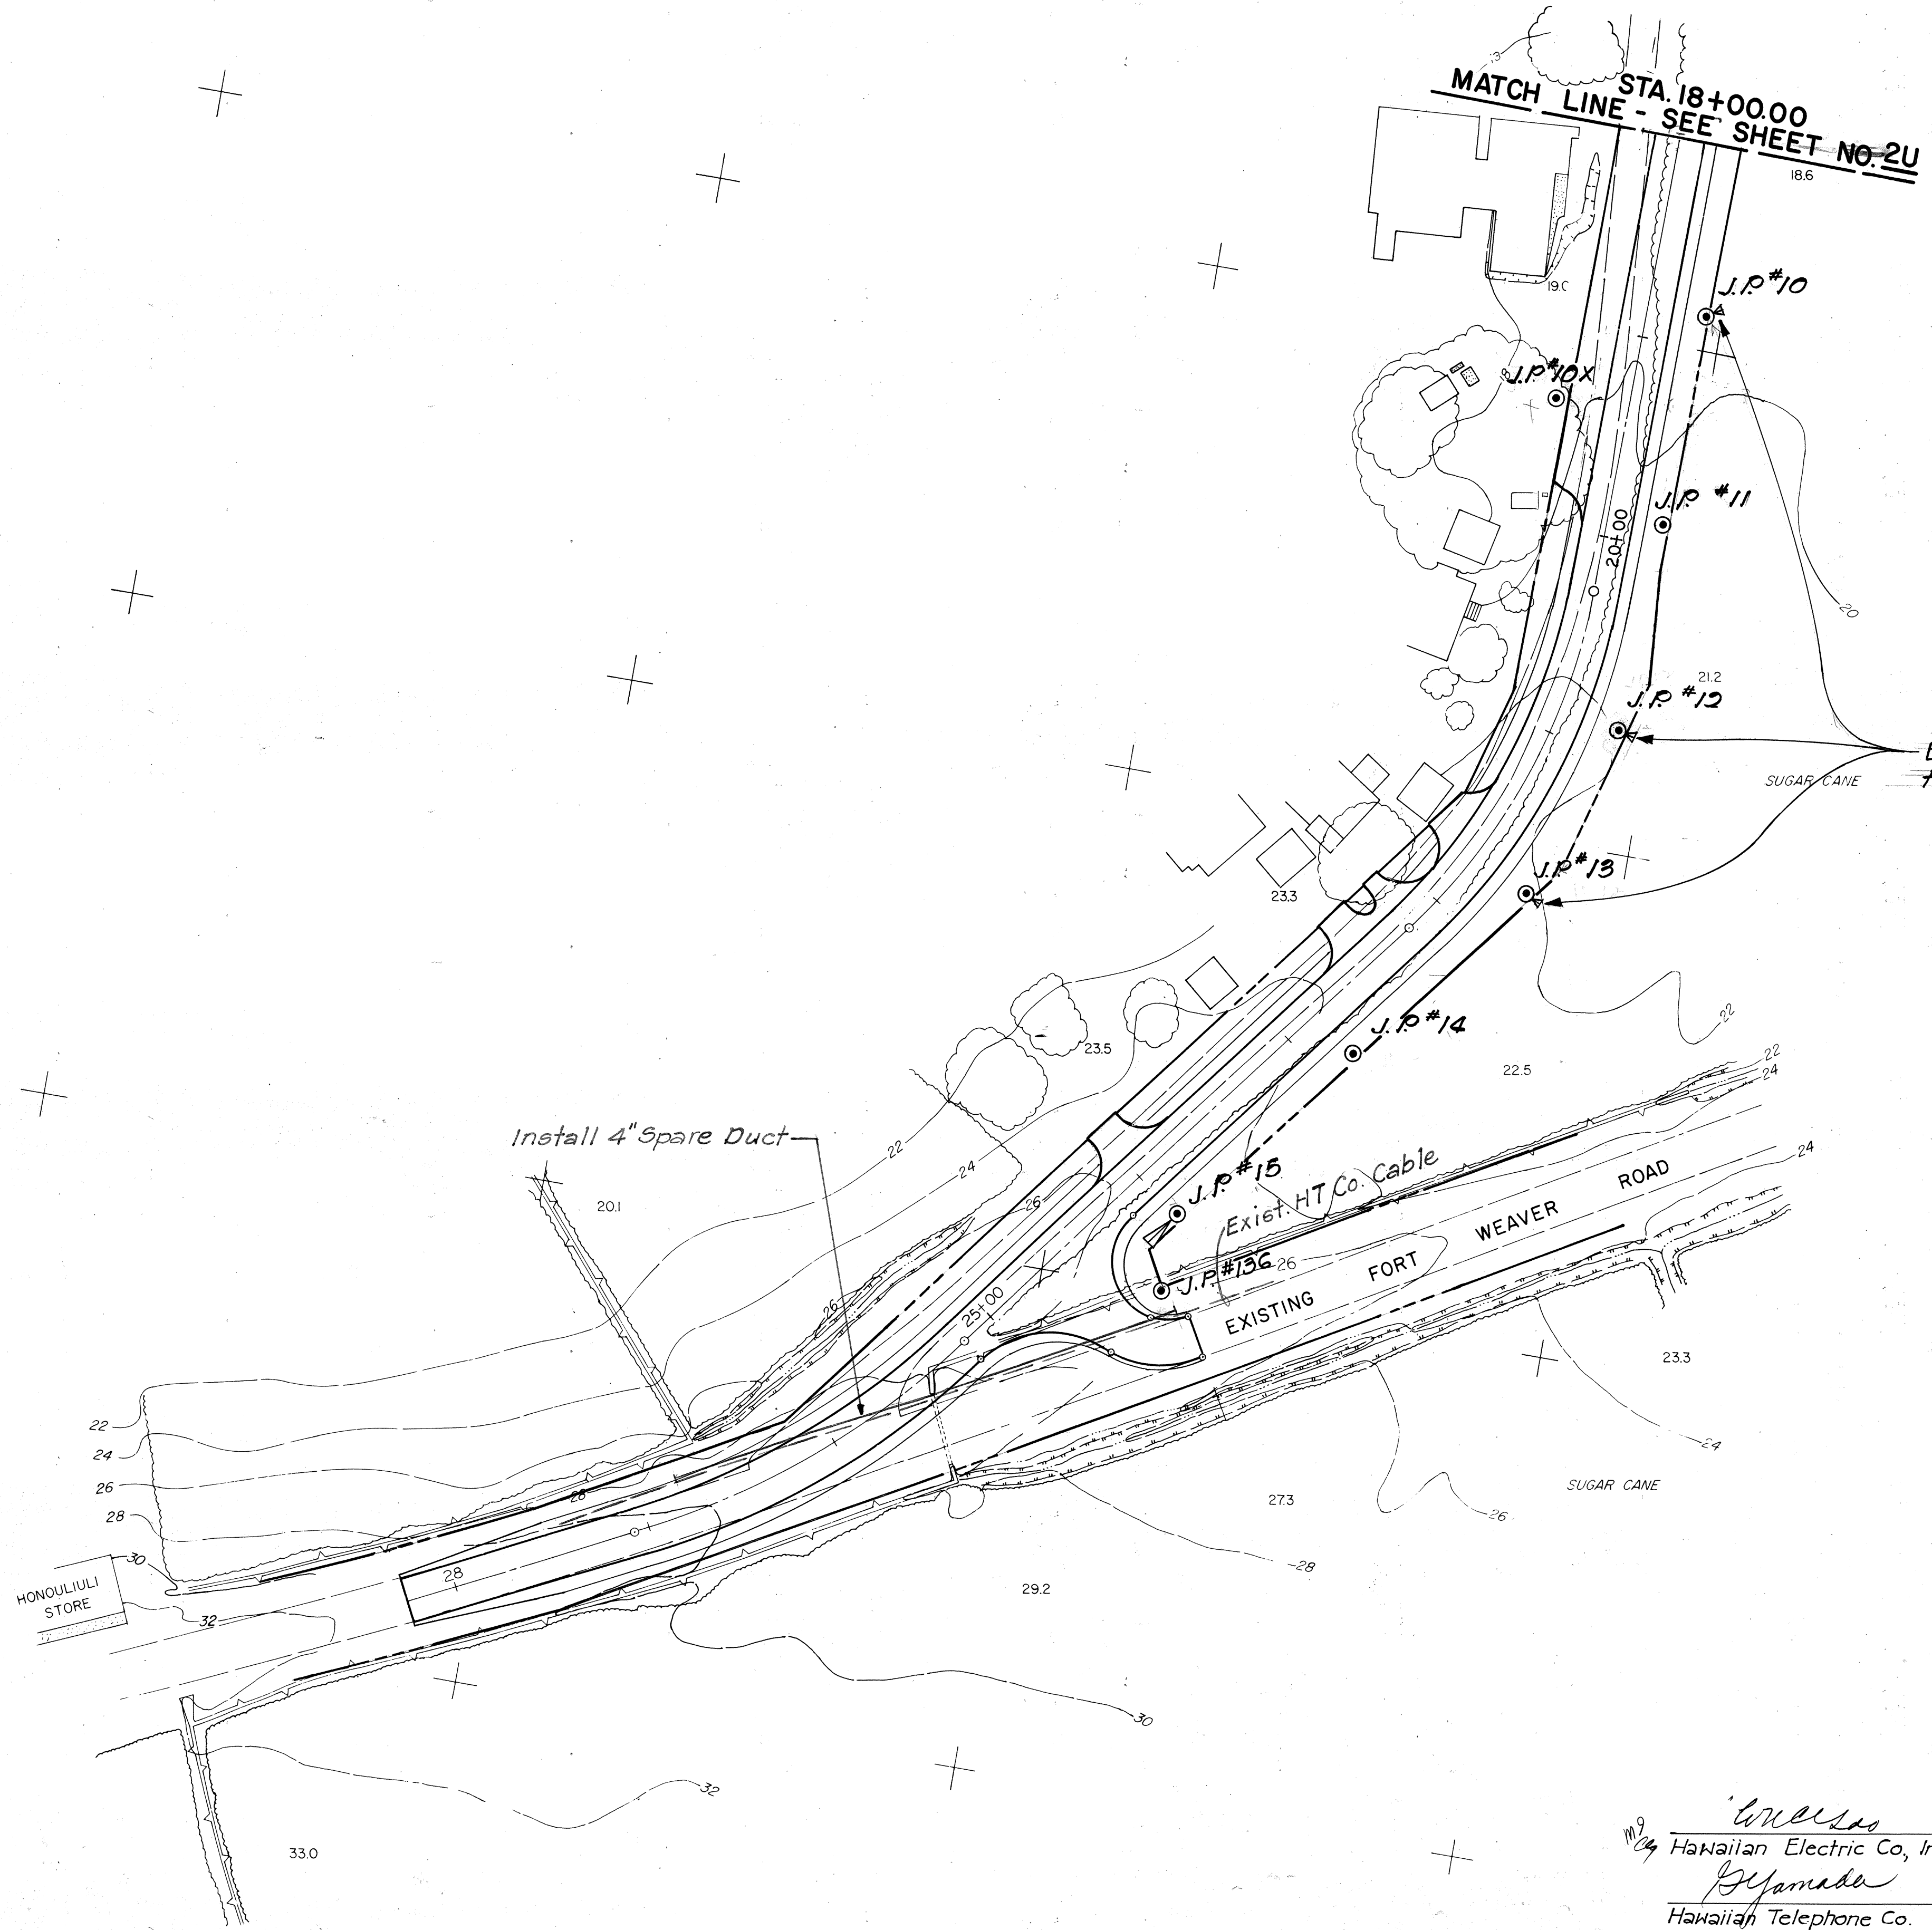

3/31/81	Replaced J.P. #9 through #12 with repositioned J.P. #10 through #15.
11/7/80	Relocated J.P. #9.
DATE	REVISION

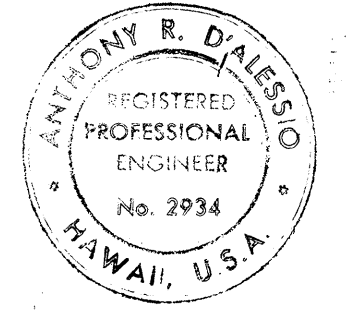

THIS WORK WAS PREPARED BY
ME UNDER MY SUPERVISION
Anthony R. D'Alessio

W. Weaver 10/24/79 Date
Hawaiian Electric Co., Inc.
Refamade 11-8-79 Date
Hawaiian Telephone Co.

STATE OF HAWAII
DEPARTMENT OF TRANSPORTATION
HIGHWAYS DIVISION
UTILITIES PLAN
RELOCATED TONGG RANCH ROAD
STA. 18+00.00 TO STA. 28+25.00
FORT WEAVER ROAD
SOUTH OF FARRINGTON HIGHWAY
TO THE VICINITY OF RENTON ROAD
SCALE: 1" = 50' DATE: SEPT 1979
SHEET NO. 3U OF 8U SHEETS

C.O. 136


SURVEY PLOTTED BY	DATE
DRAWN BY	
DESIGNED BY	
QUANTITIES BY	
CHECKED BY	
ORIGINAL PLAN	NO
NOTE BOOK	

OAHU SUGAR CO. 6" WATER LINE NOTES

- Begin Oahu Sugar Co. Water Line Sta. 0+00 = Ft. Weaver Rd. Sta. 167+00±, 68'± Rt. Remove exist. 6" Bend and Connect to 6" Main 1-6" Sleeve, 15' long (L.J.), 1-6" 1/32 Bend 8 L.F. 6" D.I. Pipe, Class 52 1-Temp. Cleanout w/ M.J. Cap (For Testing) (BWS Standards, March 77, Fig. 54)
- Oahu Sugar Co. Water Line Sta. 1+14 = Ft. Weaver Rd. Sta. 168+14±, 68'± Rt. 1-6" 1/8 Bend 1-6" 1/16 Bend 1-6" 1/32 Bend
- Oahu Sugar Co. Water Line Sta. 1+54 = Ft. Weaver Rd. Sta. 168+20±, 30'± Rt. 1-6" 1/16 Bend
- Oahu Sugar Co. Water Line Sta. 1+79 = Ft. Weaver Rd. Sta. 168+23±, 7'± Rt. 1-6" 1/32 Bend
- Oahu Sugar Co. Water Line Sta. 2+52 = Ft. Weaver Rd. Sta. 168+34±, 70'± Lt. 1-6" 1/16 Bend
- Oahu Sugar Co. Water Line Sta. 2+80 = Ft. Weaver Rd. Sta. 168+39±, 100'± Lt. 2-6" 1/8 Bends 5 L.F. 6" D.I. Pipe, Class 52
- Oahu Sugar Co. Water Line Sta. 2+85 = Ft. Weaver Rd. Sta. 168+41±, 103'± Lt. 1-6" 1/16 Bend, 1-6" Sleeve, 15' Long (L.J.) 8 L.F. 6" D.I. Pipe, Class 52 1-Temp. Cleanout w/ M.J. Cap (For Testing) (BWS Standards, March 77, Fig. 54)


NOTES: a. Contractor shall determine the exact location and elevation of tie-in points and ⑦ prior to performing any work on Oahu Sugar Company 6-Inch Water Line.

b. 2 1/2" depth of lead for lead joint pipe required at all embedded joints. Wherever construction joints are required 6" rubber or neoprene waterstops shall be installed. Waterstop shall be of the type specified and manufactured by the Kirkhill Rubber Company, or approved equal.

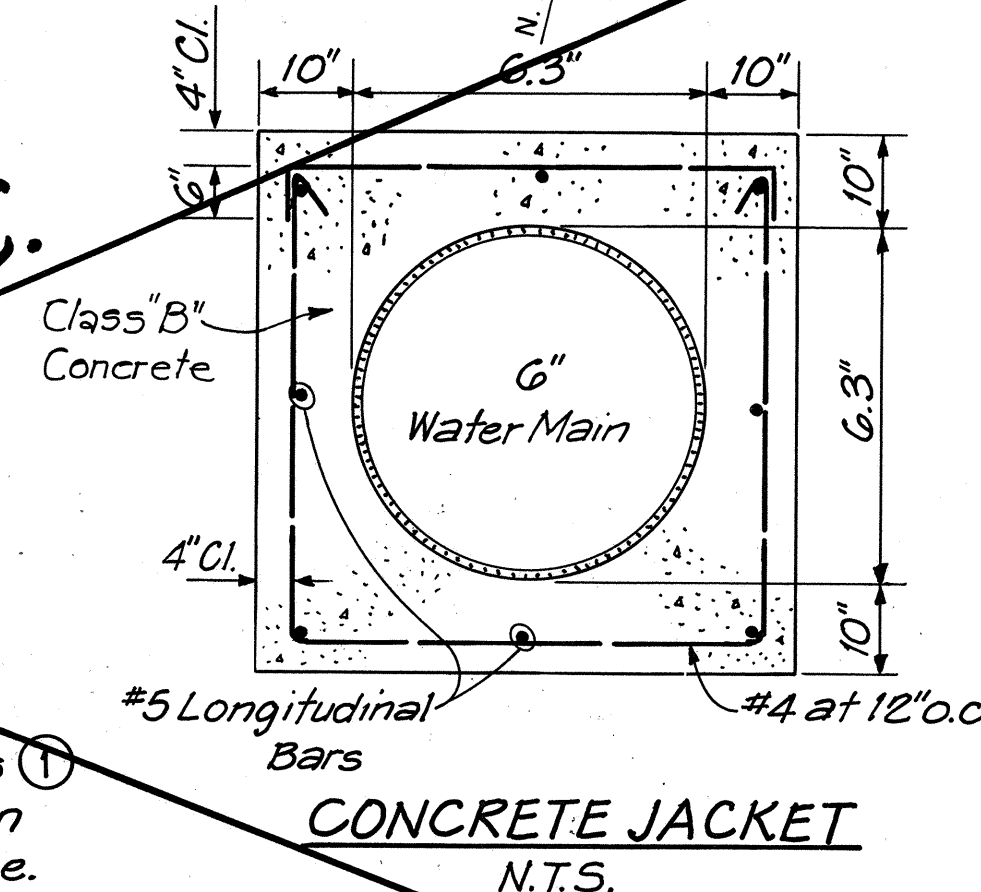

CONCRETE SLAB DETAIL FOR METER BOX IN DIRT AREA (BWS) N.T.S.

DATE	REVISION	FED. ROAD DIST. NO.	STATE	FED. AID PROJ. NO.	FISCAL YEAR	SHEET NO.	TOTAL SHEETS
6/23/81	Repositioned J.P. #141X, 142X & 143. Added Anchors to J.P. #141, 142 & 143X. Deleted Adjustments to Signal Corps Cables at Sta. 162+50 Rt. Added Reference Note for new Sht. C.O. 1395-1. Deleted HTCo. Pullbox at J.P. #142. Added BWS Reapproval Block.	HAWAII	HAW.	M-7600(2)	1980	137	244

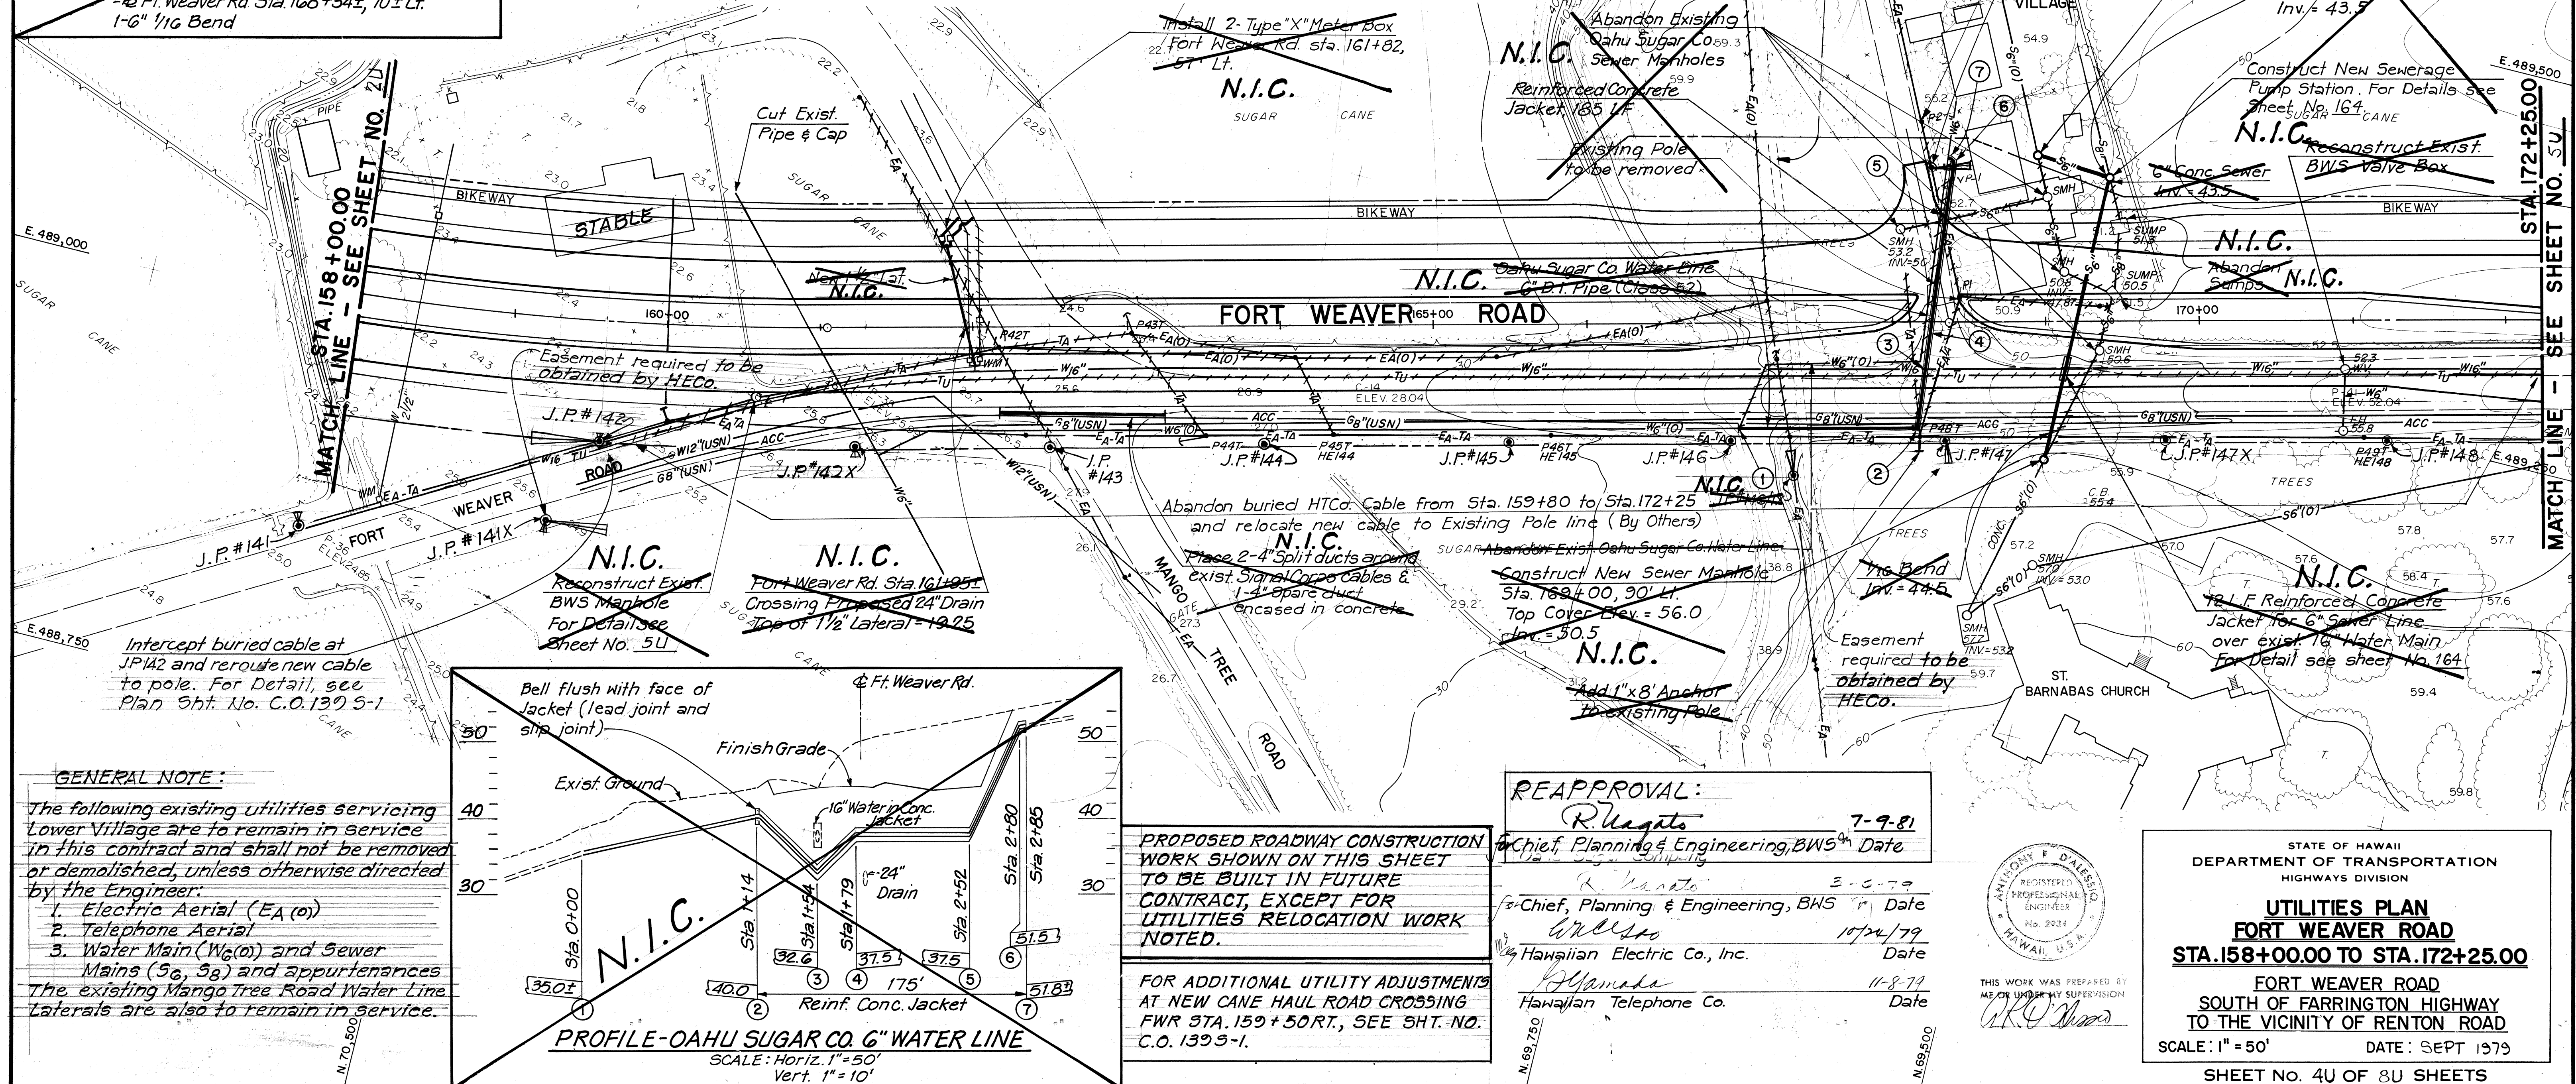


GENERAL NOTE:

The following existing utilities servicing Lower Village are to remain in service in this contract and shall not be removed or demolished, unless otherwise directed by the Engineer:

- Electric Aerial (EA (a))
- Telephone Aerial
- Water Main (Wg (a)) and Sewer Mains (Sg, Sg) and appurtenances

The existing Mango Tree Road Water Line Laterals are also to remain in service.

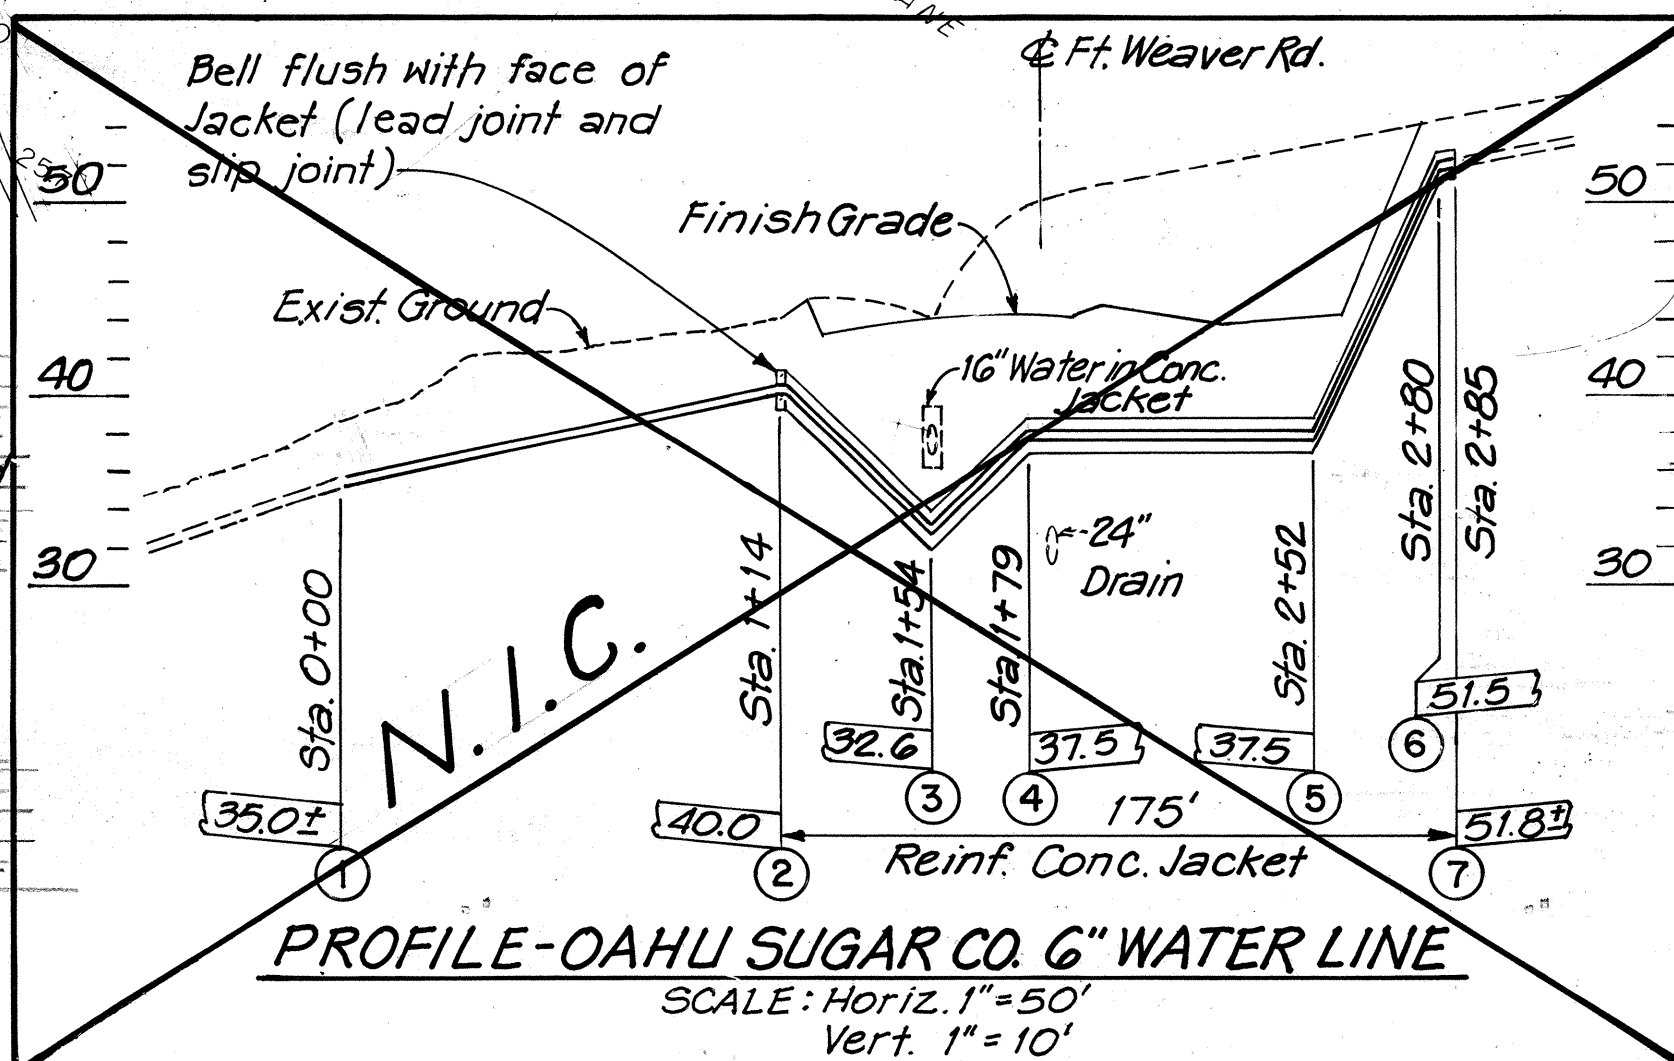


PROPOSED ROADWAY CONSTRUCTION WORK SHOWN ON THIS SHEET TO BE BUILT IN FUTURE CONTRACT, EXCEPT FOR UTILITIES RELOCATION WORK NOTED.

FOR ADDITIONAL UTILITY ADJUSTMENTS AT NEW CANE HAUL ROAD CROSSING FWR STA. 159+50 RT., SEE SHT. NO. C.O. 1395-1.

REAPPROVAL: R. Ugata 7-9-81 Chief, Planning & Engineering, BWS Date

Hawaiian Electric Co., Inc. 3-5-79 Date
Hawaiian Telephone Co. 10/24/79 Date
11-8-77 Date

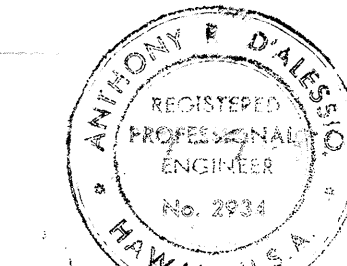

STATE OF HAWAII
DEPARTMENT OF TRANSPORTATION
HIGHWAYS DIVISION

UTILITIES PLAN
FORT WEAVER ROAD
STA. 158+00.00 TO STA. 172+25.00


FORT WEAVER ROAD
SOUTH OF FARRINGTON HIGHWAY
TO THE VICINITY OF RENTON ROAD

SCALE: 1" = 50' DATE: SEPT 1979

SHEET NO. 4U OF 8U SHEETS

C.O. 137

FED. ROAD DIST. NO.	STATE	FED. AID PROJ. NO.	FISCAL YEAR	SHEET NO.	TOTAL SHEETS
HAWAII	HAW.	M-7600(2)	1980	138	244

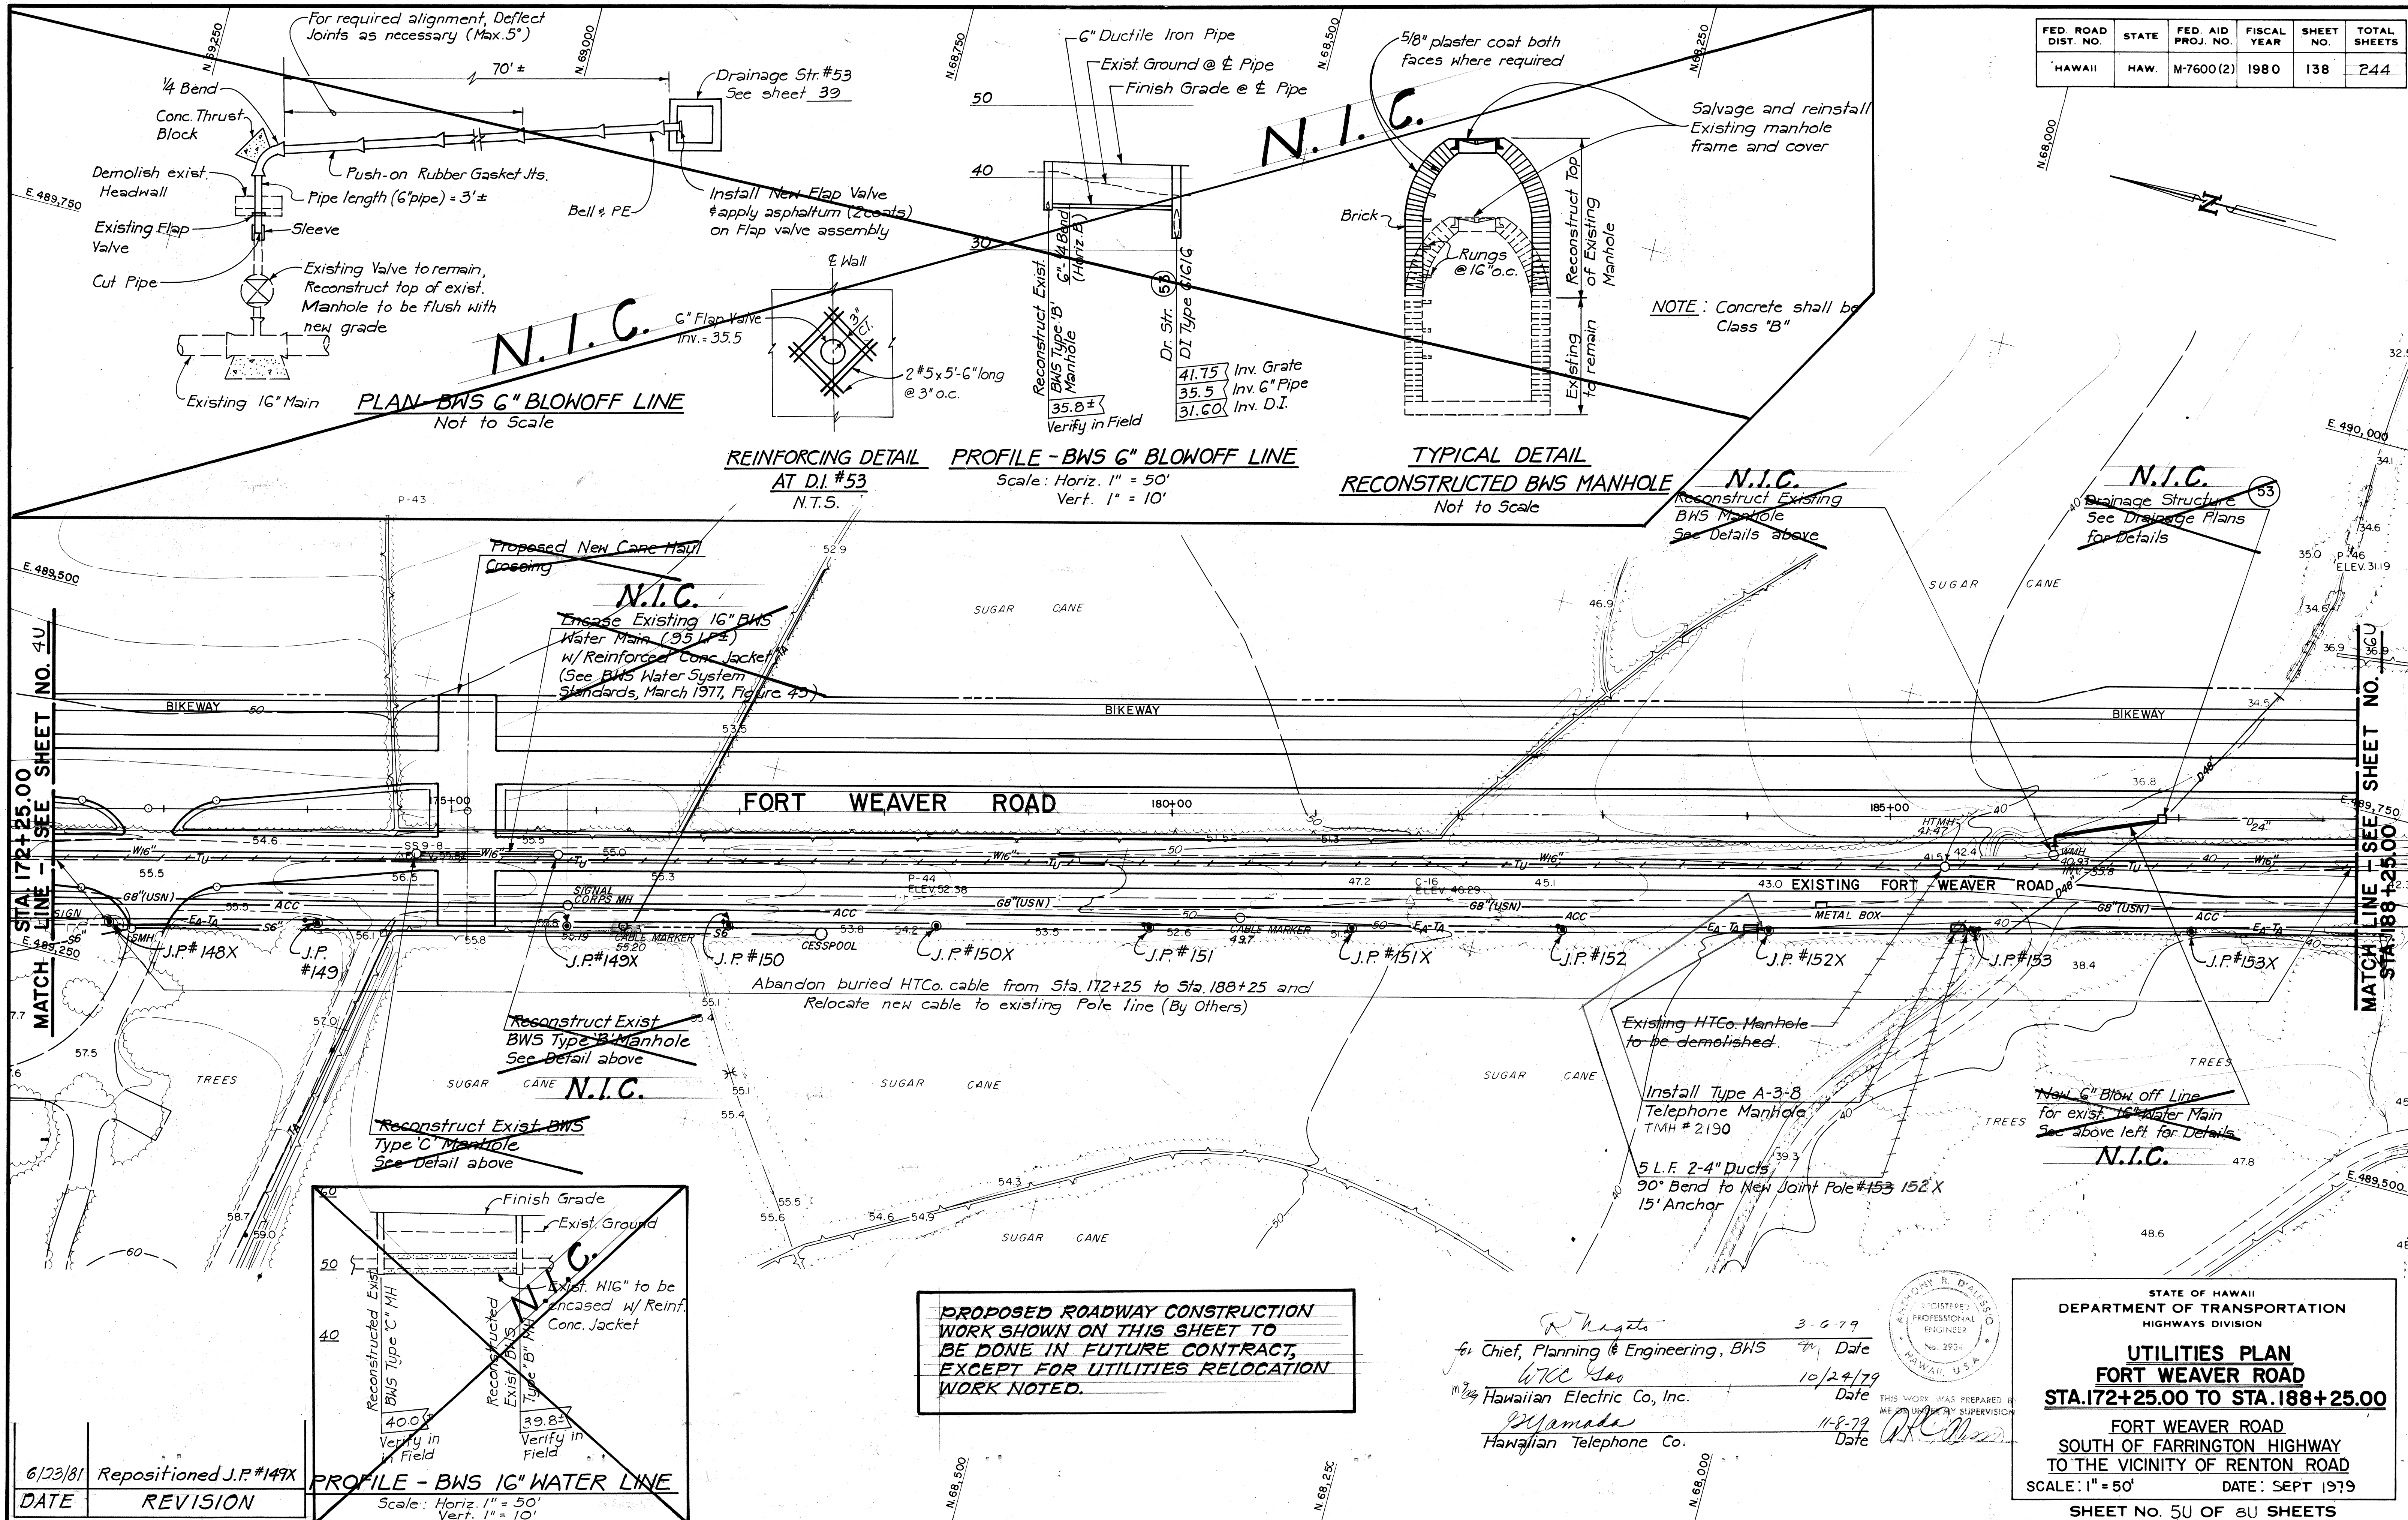

CONSTRUCTION PHASING NOTES

1. State's Contractor to expose existing ductline as required under HECO's supervision.
2. HECO to break the concrete encasement around the exist. ducts which are to remain in place as a protective guard for the existing energized 12 KV Cables.
3. State's Contractor to construct the 4x6 handhole over the exposed ductline under HECO's supervision and to construct the new duct system to proposed pole (J.P. 156/1).
4. HECO to install and remove cables and to break the existing ducts upon completion of the 4x6 handhole and the duct system by the State's Contractor.

U.S. NAVY ELECT. NOTES

1. Contractor shall notify Roy Higa (Ph. 471-3549) or Robert Tamura (Ph. 471-0125) of Navy Public Works Center before commencing work.
2. Removed materials shall be abandoned.
3. Contractor shall stake out new pole & anchor location for Navy's approval before installation.
4. New pole shall be Class 3, fully creosoted by the pressure method. Anchor shall be 3/4" x 8.0' galv. anchor rod with 18" deadman; see detail on Sht. No. 143.
5. Contractor shall furnish & install primary metering equipment in accordance with HECO Eng. Std. 4-5000, except that the inside potential transformer shall be deleted. Provide two meter sockets, one each KWH & KVARH, at mounting height of 5.0' min. & 7.0' max. Both sockets shall be 13-Jaw (see HECO Cat. No. 121413). Circle AW Type. All sockets shall be grounded per HECO Std.

Telephone Pullbox, Type 43GT

Locate new Pullbox to intercept exist. telephone duct (Telephone Line 'C') (Work Performed by HECO Forces) Electric Handhole #1, Type 46 (HECO Dwg 18842) Locate new handhole to intercept existing electric duct. See Construction Phasing Notes and Special Note to State's Contractor. (Electric Line 'A')

Contractor to Furn. & Install 45' Primary Meter Pole at FWR Sta. 194+42, 278' Lt., with 18" Anchor. Connect Cable from Pole PH-4. See U.S.N. Elect. Notes, this Sht.

SPECIAL NOTE TO STATE'S CONTRACTOR

The existing cables which are in ductlines are energized. These energized insulated cables are to remain in place during Construction. Only HECO Men are to handle these cables and to erect temporary Guards to protect these cables from damages. Contractor to exercise due care and precautions to avoid disturbance of energized cables, temporary guards, etc. and shall work cautiously to avoid accidents.


STANDARD OIL NOTES (CHEVRON USA INC.)

1. All costs pertaining to damage of the pipelines, their coatings, or their cathodic protection devices or damage of property and injury to persons caused directly or indirectly by this work, will be charged to the Contractor.
2. Trenches across pipelines shall be limited to a maximum width of 5 feet unless the lines are supported in a manner acceptable to Chevron U.S.A. Inc.
3. All excavations and backfilling operations in Chevron U.S.A. Inc. easements must be witnessed by a Chevron Representative. All backfill material within 6 inches of the pipelines must be of finely graded dirt or sand. All excavations within 2 feet of pipelines must be accomplished by hand digging. Work shall be handled in an expeditious manner in order to keep the pipeline uncovered for as short a period as possible.
4. The Contractor shall notify Chevron USA Inc. by calling 682-5711 2 weeks before beginning any work within Chevron USA Inc. easement.

FED. ROAD DIST. NO.	STATE	FED. AID PROJ. NO.	FISCAL YEAR	SHEET NO.	TOTAL SHEETS
HAWAII	HAW.	M-7600(2)	1980	139	244

SEE SHEET NO. 150 STA. 188+25.00

STA. 204+50.00 END PROJECT NO. M-7600(2)

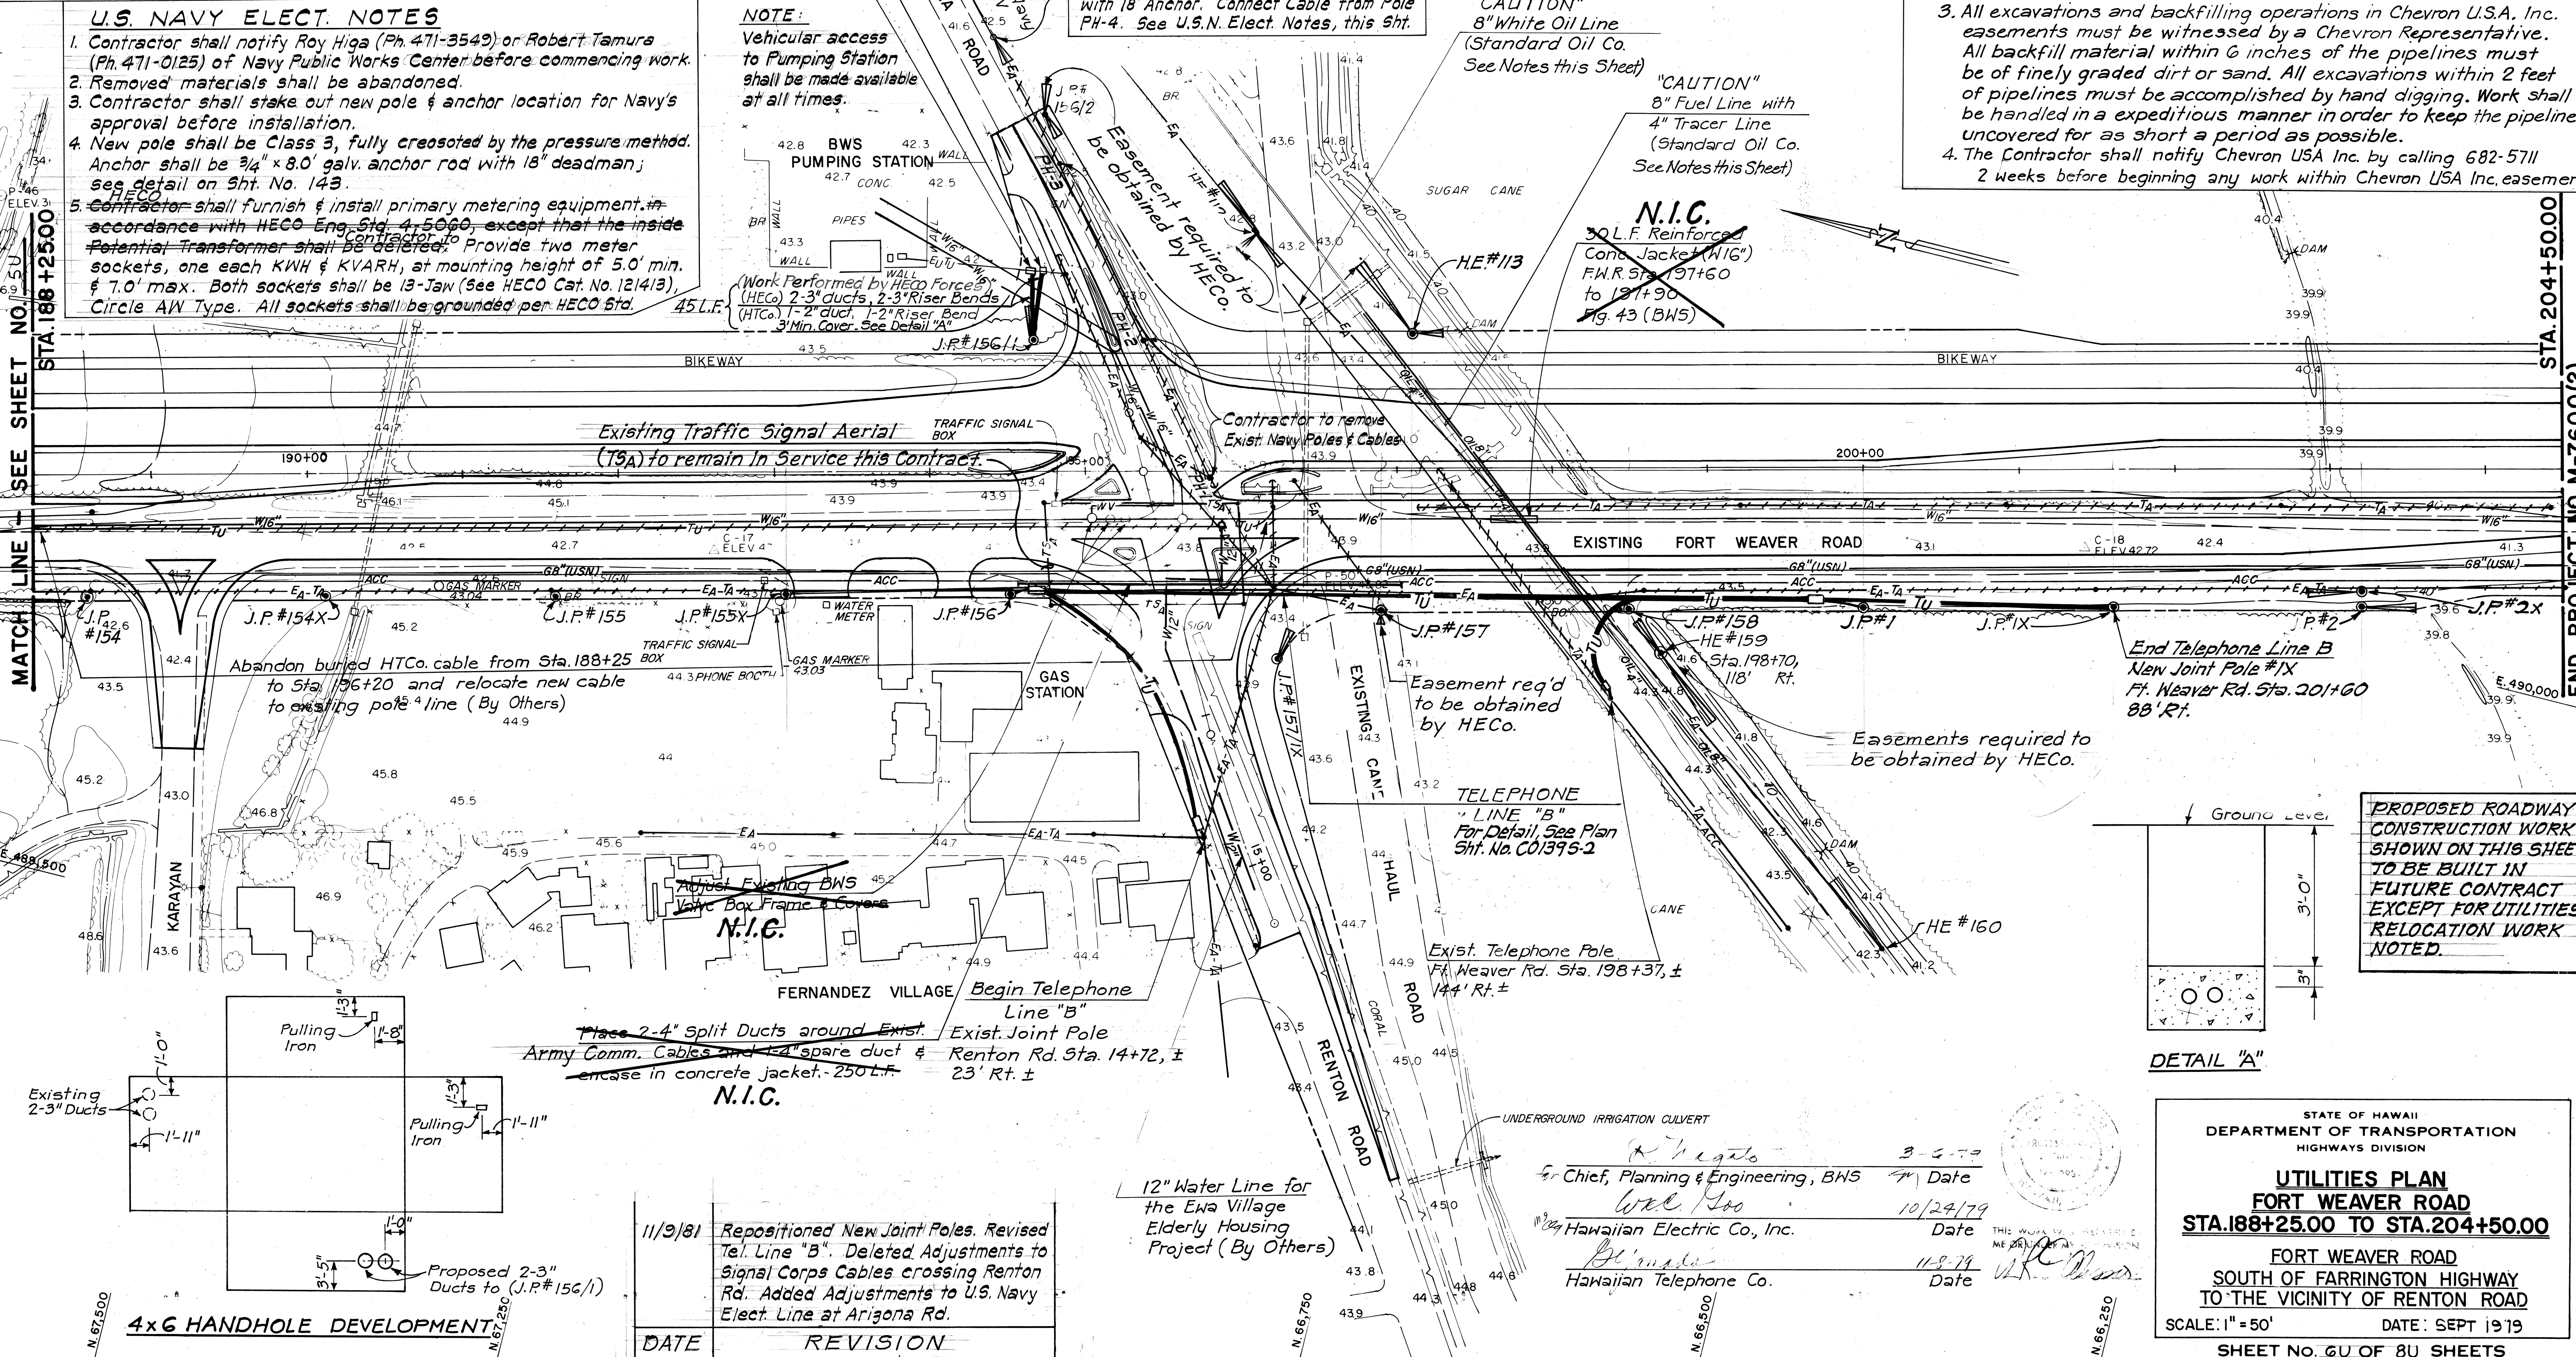

PROPOSED ROADWAY CONSTRUCTION WORK SHOWN ON THIS SHEET TO BE BUILT IN FUTURE CONTRACT EXCEPT FOR UTILITIES RELOCATION WORK NOTED.

DETAIL "A"

STATE OF HAWAII
DEPARTMENT OF TRANSPORTATION
HIGHWAYS DIVISION

UTILITIES PLAN
FORT WEAVER ROAD
STA. 188+25.00 TO STA. 204+50.00

FORT WEAVER ROAD
SOUTH OF FARRINGTON HIGHWAY
TO THE VICINITY OF RENTON ROAD

SCALE: 1" = 50' DATE: SEPT 1979
SHEET NO. 60 OF 80 SHEETS


DATE	REVISION
11/9/81	Repositioned New Joint Poles. Revised Tel. Line "B". Deleted Adjustments to Signal Corps Cables crossing Renton Rd. Added Adjustments to U.S. Navy Elect. Line at Arizona Rd.

Chief, Planning & Engineering, BNS
Hawaiian Electric Co., Inc.
Hawaiian Telephone Co.

3-5-79
10/24/79
11-8-79


12" Water Line for the Ewa Village Elderly Housing Project (By Others)

4x6 HANDHOLE DEVELOPMENT

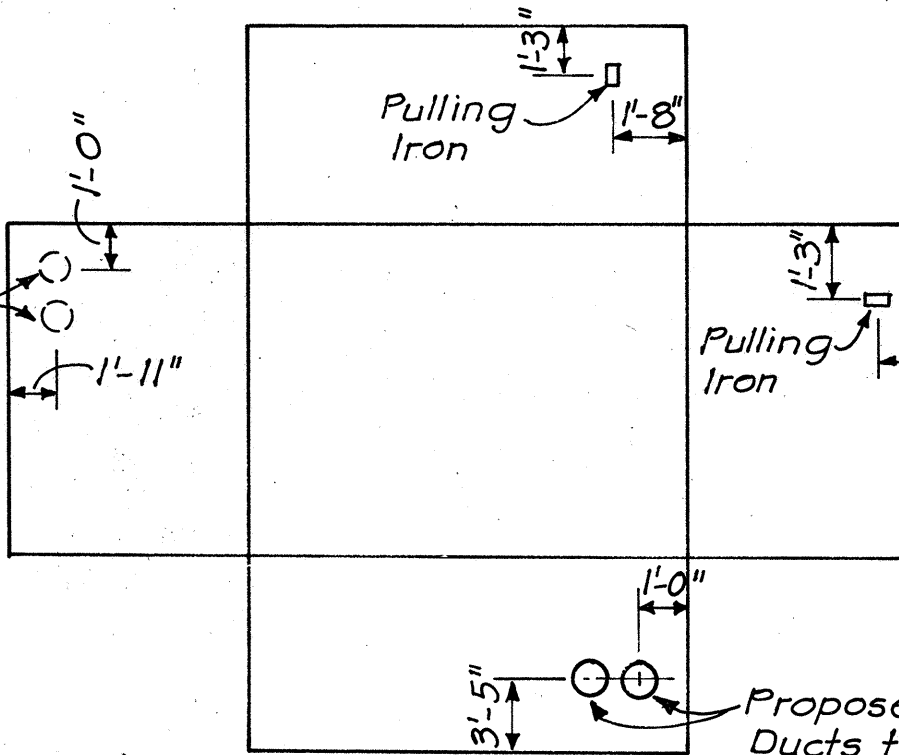

DATE	BY	REVISION
	DESIGNED BY	
	DRAWN BY	
	CHECKED BY	
	QUANTITIES BY	
	NOTE BOOK	
	NO.	

FED. ROAD DIST. NO.	STATE	FED. AID PROJ. NO.	FISCAL YEAR	SHEET NO.	TOTAL SHEETS
HAWAII	HAW.	M-7200(2)	1981	C.O.1395-1	244

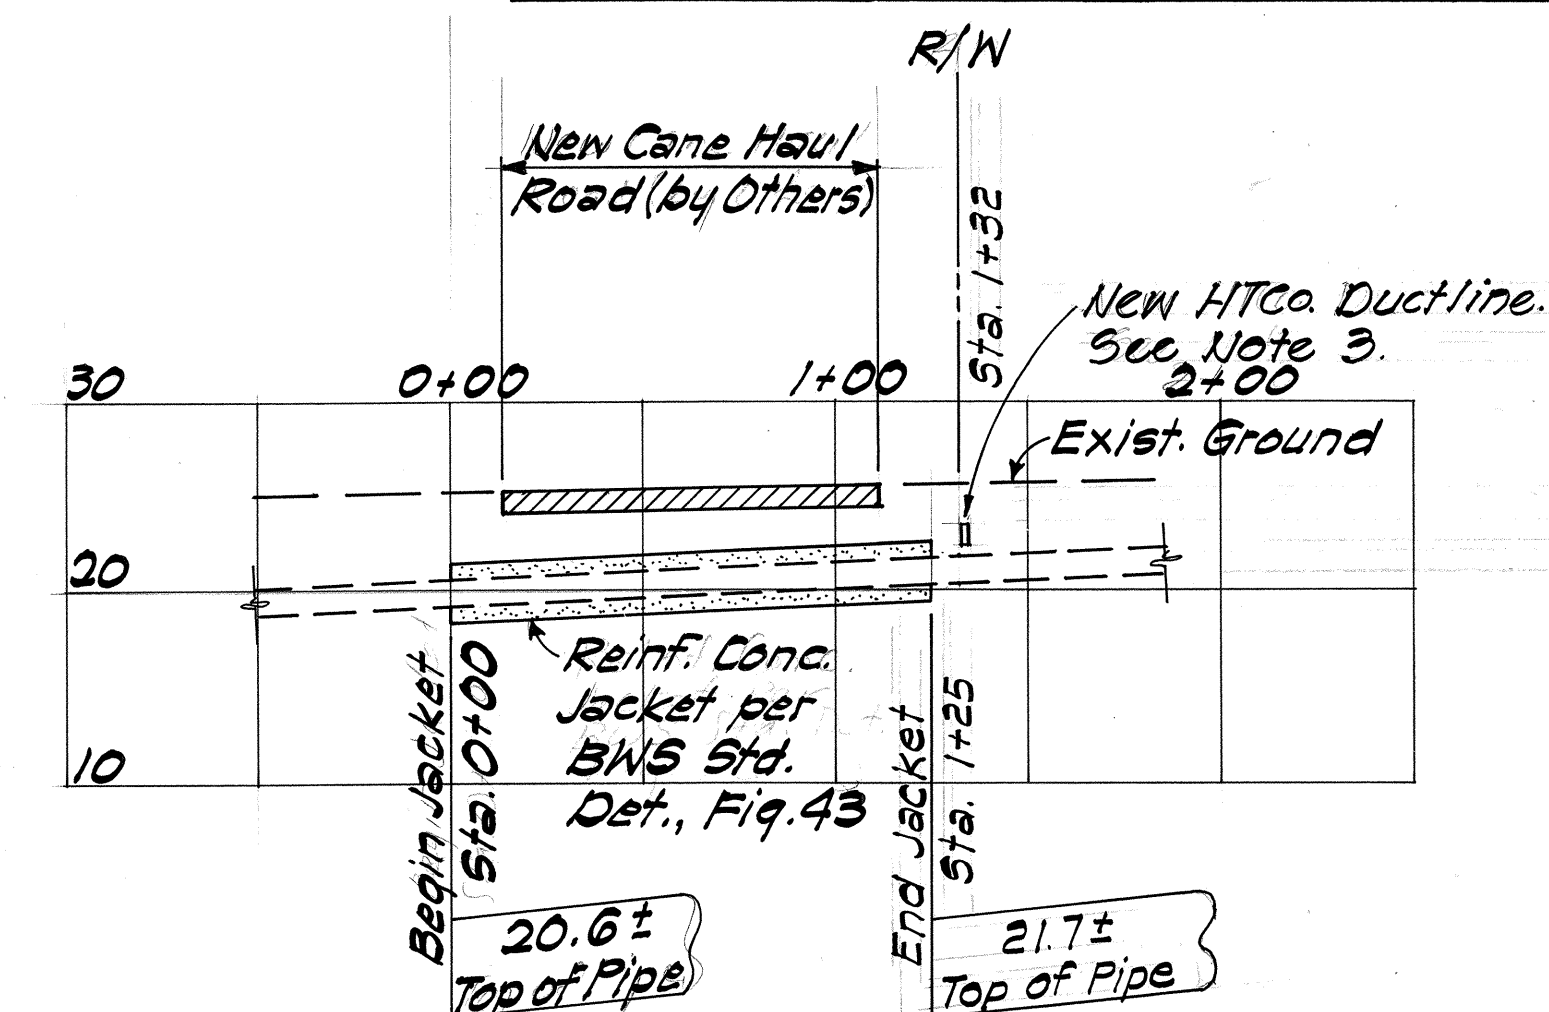


PROFILE - BWS 16" MAIN

Scale: Horiz. 1" = 50'
Vert. 1" = 10'


BWS NOTES

1. Maintain 3.0' minimum cover from top of pipe.
2. Extend reinf. conc. jacket as necessary to terminate at the closest pipe joint.
3. Provide 6" min. clearance bet ductline & water main.

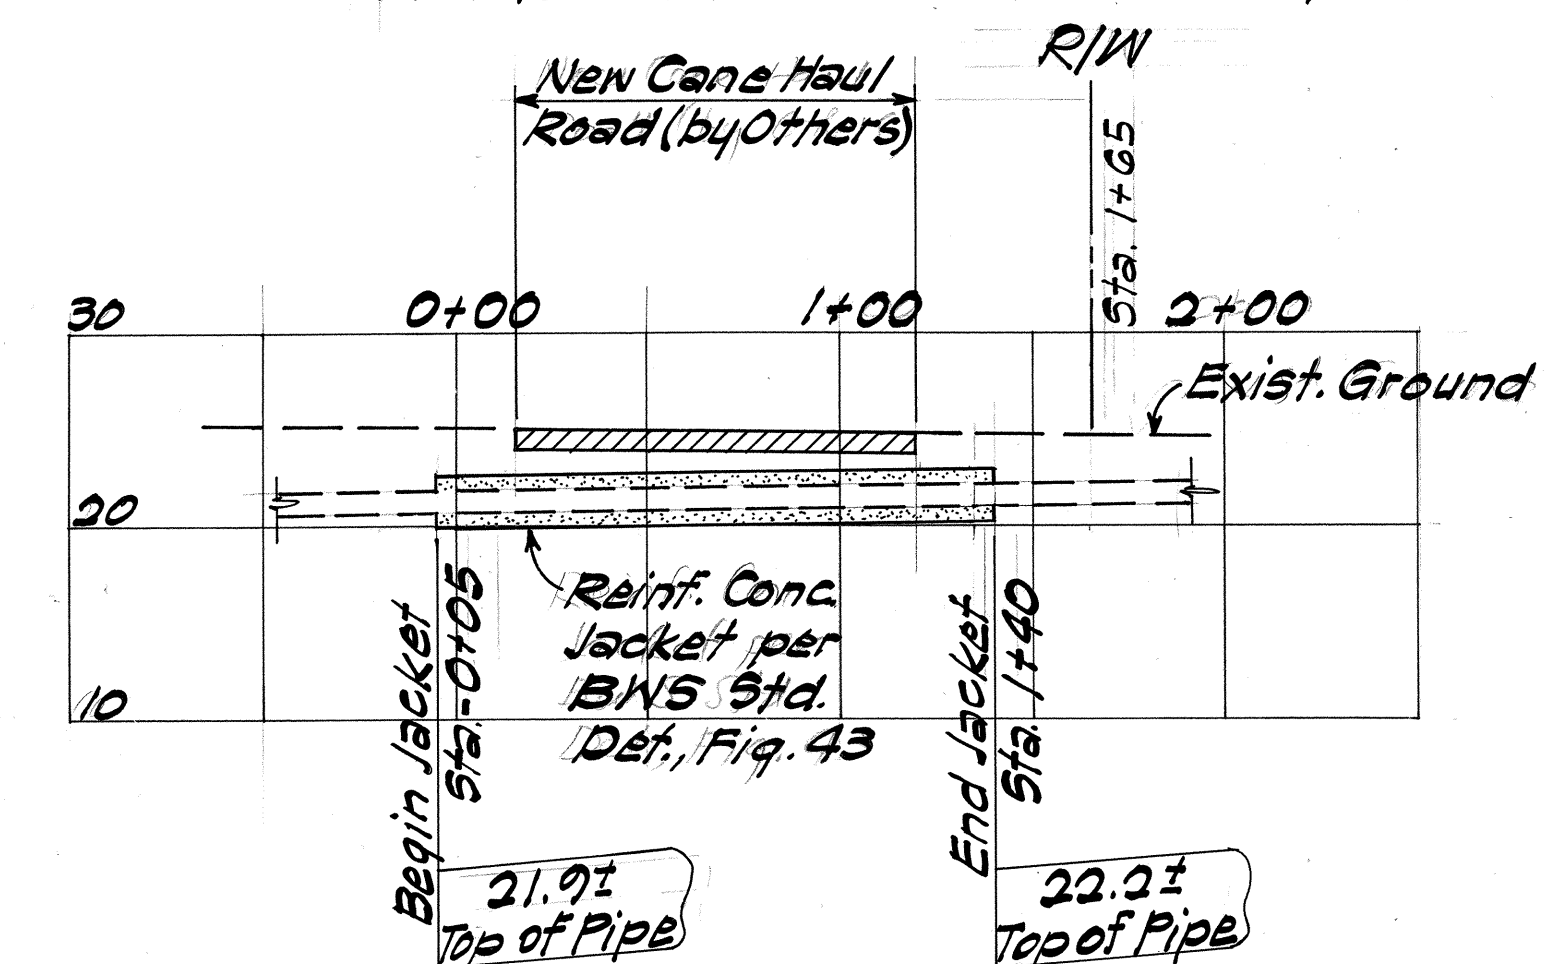

PROFILE - USN 12" MAIN

Scale: Horiz. 1" = 50'
Vert. 1" = 10'

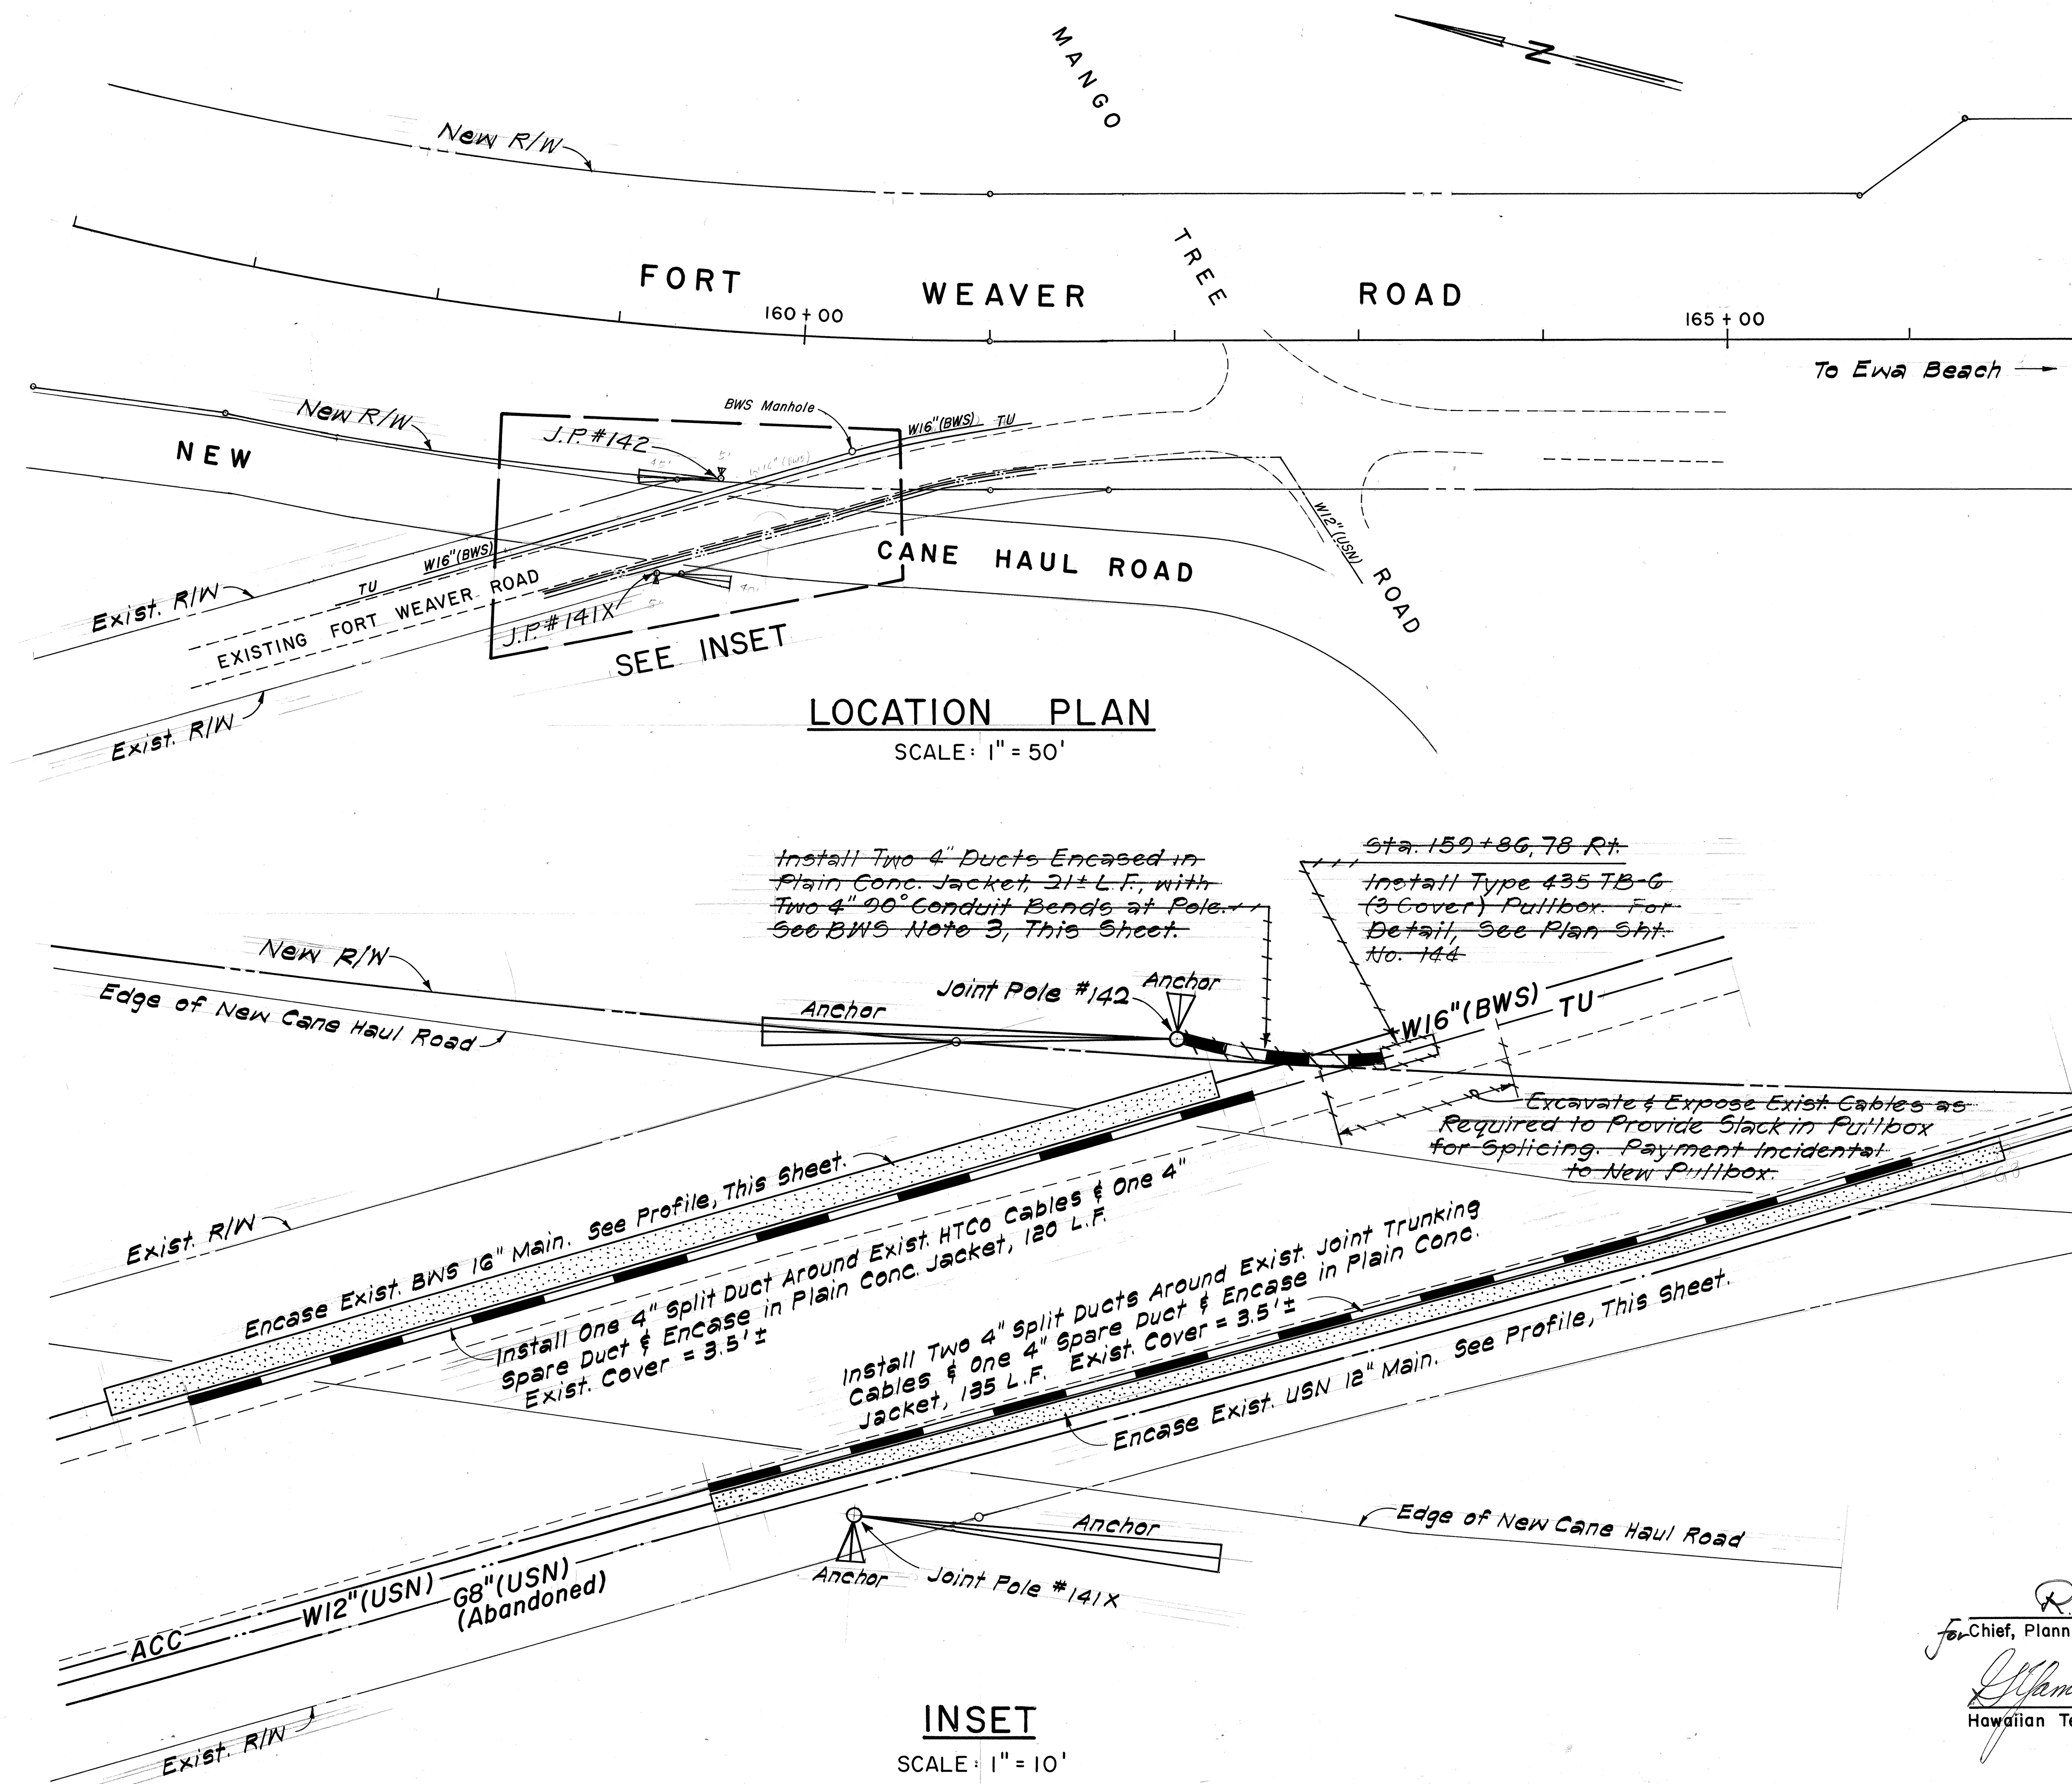

LOCATION PLAN

SCALE: 1" = 50'

INSET

SCALE: 1" = 10'


SURVEY PLOTTED BY	DATE
DRAWN BY	
TRACED BY	
CHECKED BY	
NOTE BOOK	
NO.	

R. Uagato
for Chief, Planning & Engineering, BWS
Date 7-9-81
L. Hamada
Hawaiian Telephone Co.
Date 7-30-81




STATE OF HAWAII
DEPARTMENT OF TRANSPORTATION
LAND TRANSPORTATION FACILITIES DIVISION
UTILITIES PLAN
FORT WEAVER ROAD
NEW CANE HAUL ROAD CROSSING
FORT WEAVER ROAD
SOUTH OF FARRINGTON HIGHWAY
TO THE VICINITY OF RENTON ROAD
SCALES: AS SHOWN DATE: JUNE 1981
SHEET NO. 6U OF 8U SHEETS

C.O.1395-1

FED. ROAD DIST. NO.	STATE	FED. AID PROJ. NO.	FISCAL YEAR	SHEET NO.	TOTAL SHEETS
HAWAII	HAW.	M-7600(2)	1982	CO 139 S-2	244

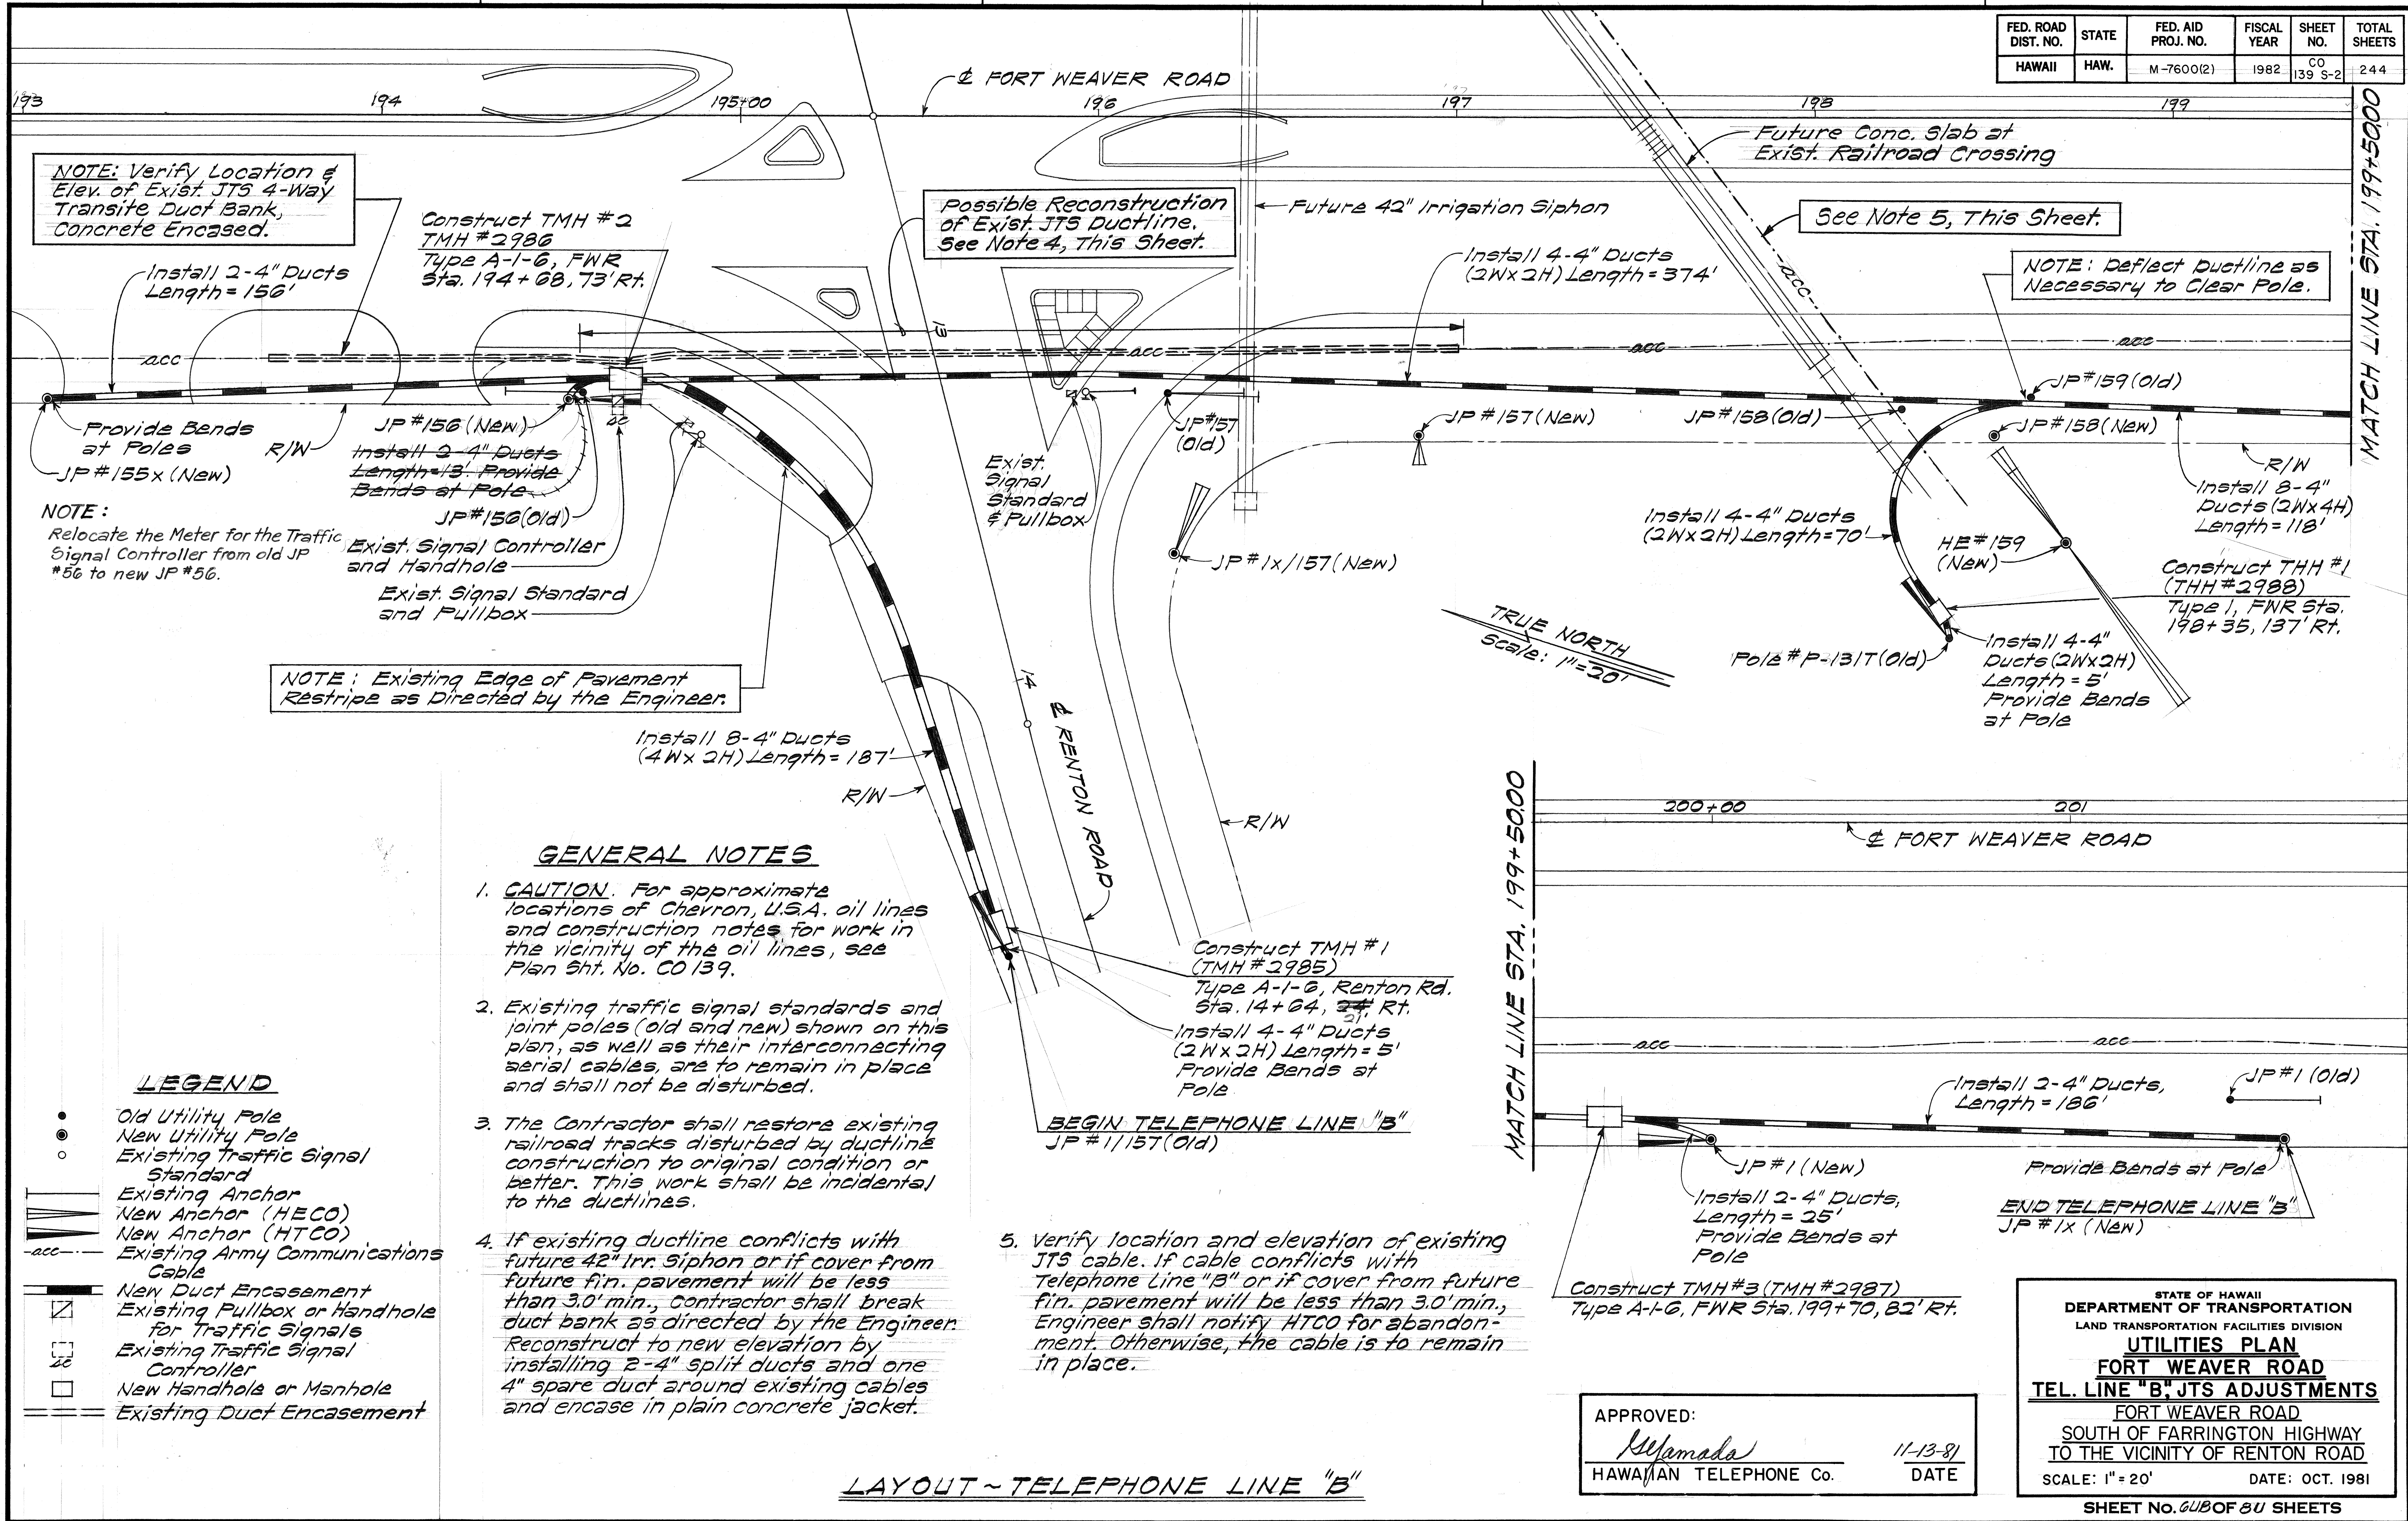

FED. ROAD DIST. NO.	STATE	FED. AID PROJ. NO.	FISCAL YEAR	SHEET NO.	TOTAL SHEETS
HAWAII	HAW.	M-7600(2)	1980	140	244

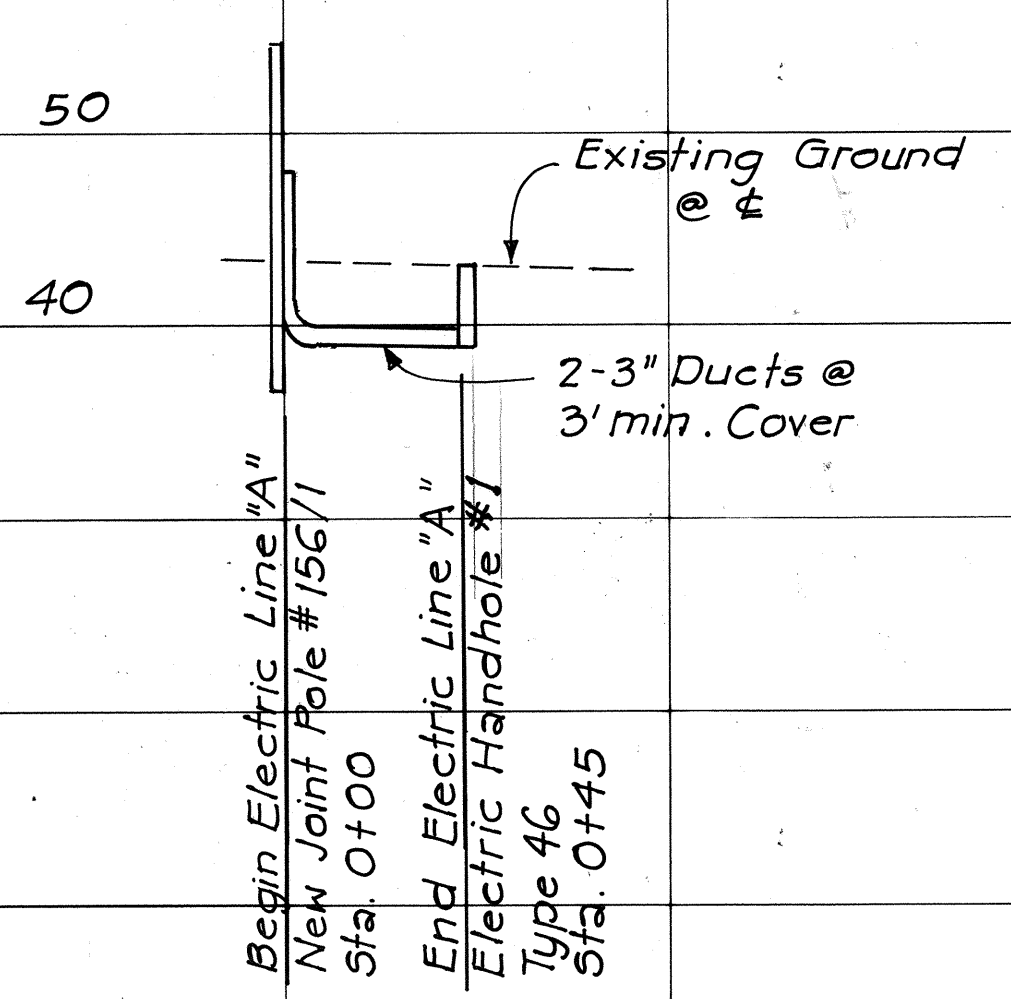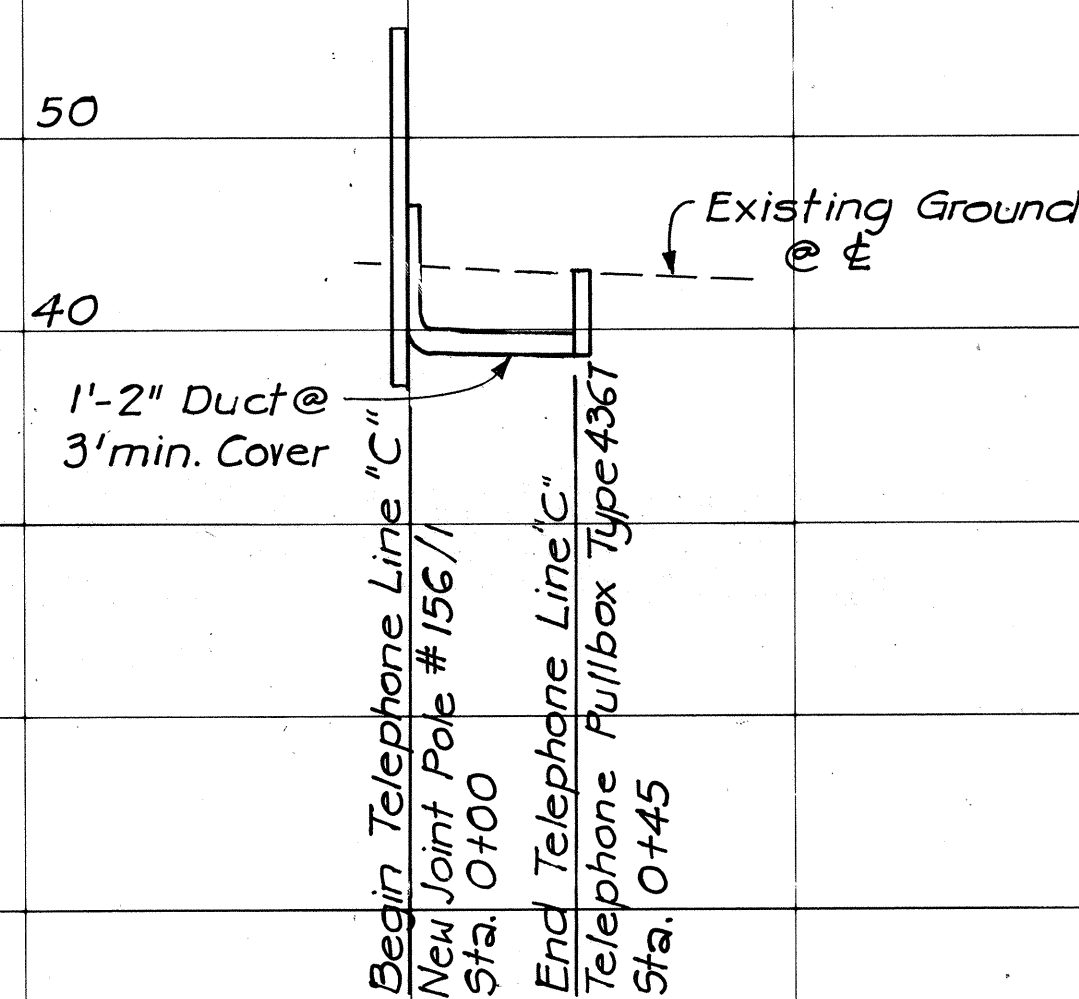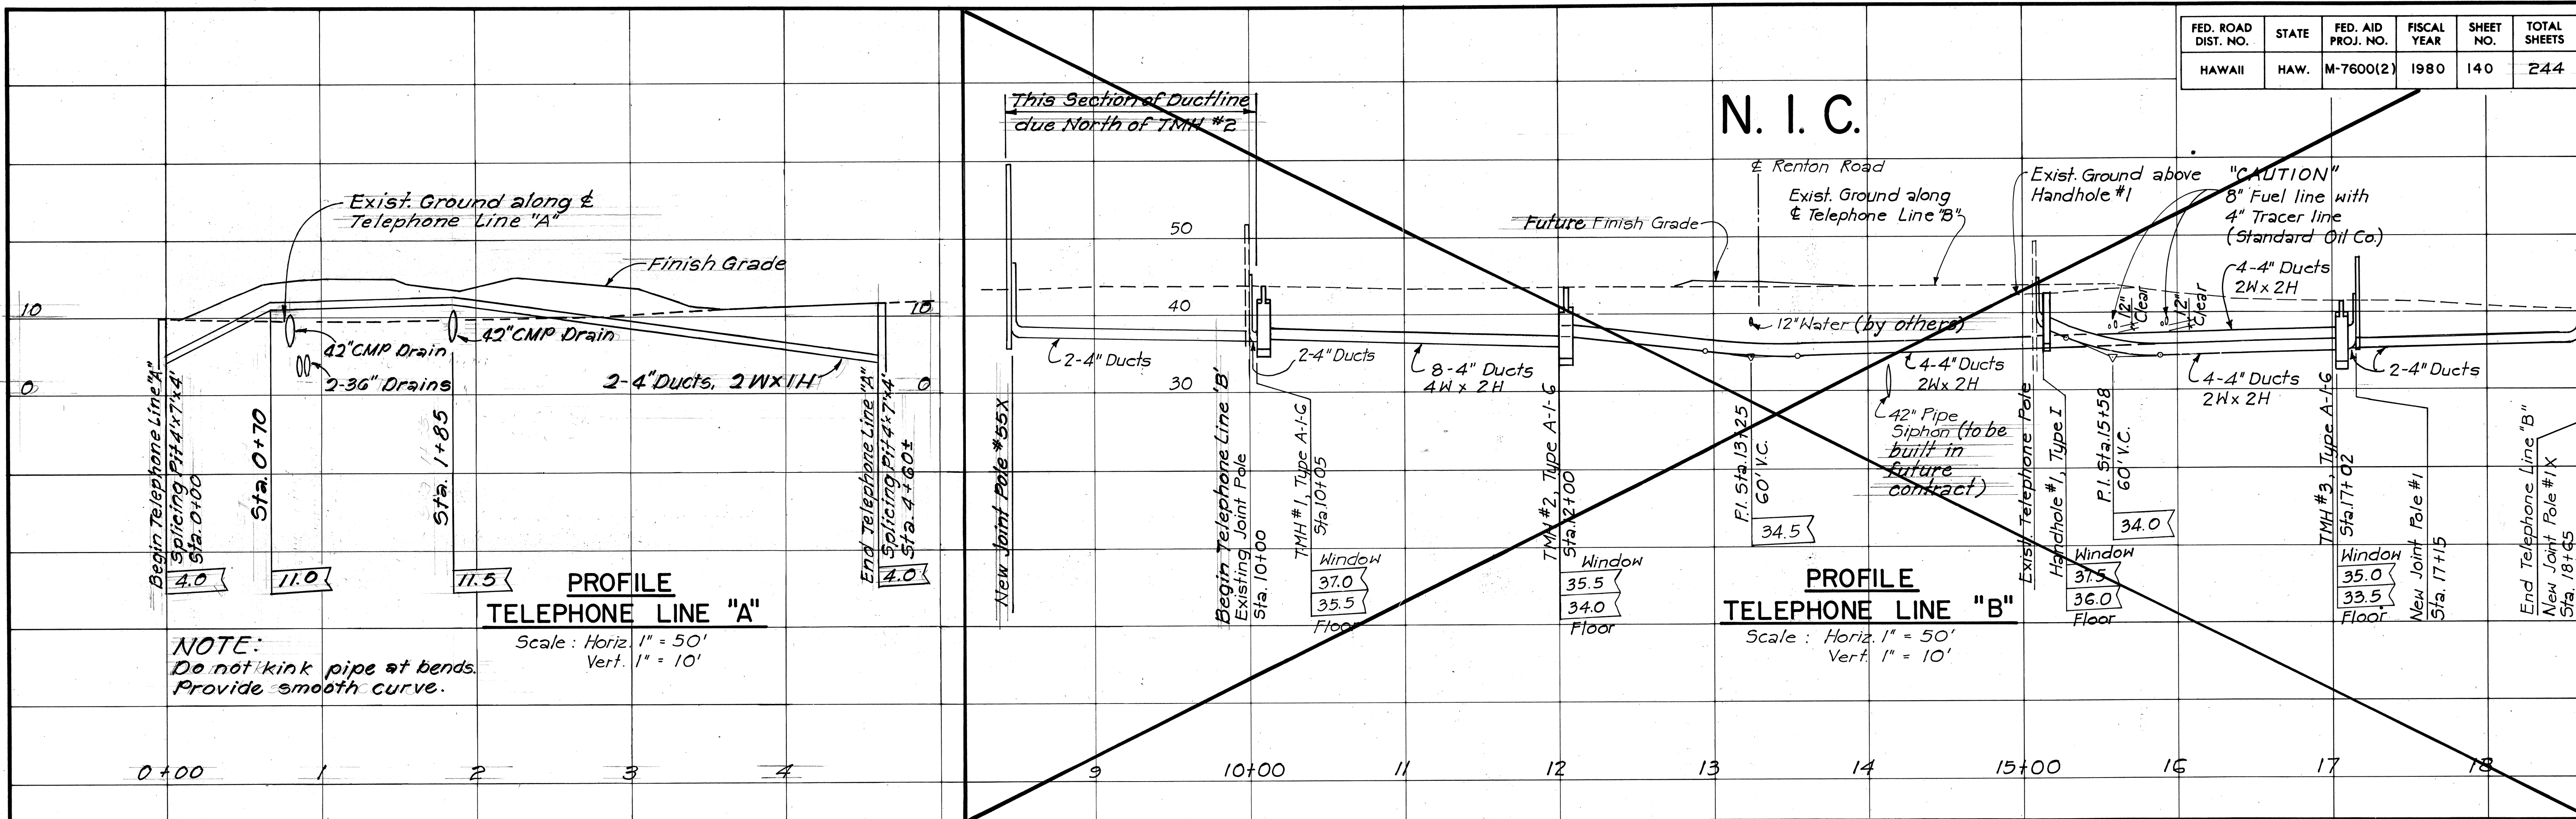


(Work Performed by HECO Forces)

W. Wilson
Hawaiian Electric Co.

2-22-80
Date

K. Yamada
Hawaiian Telephone Co.

11-8-79
Date

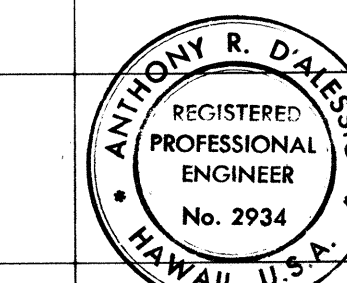

THIS WORK WAS PREPARED BY ME OR UNDER MY SUPERVISION.

DATE	REVISION
11/2/81	Deleted Profile-Telephone Line "B"
3/31/81	Second Revision to Telephone Line "A" Profile.
2/4/81	Revised Telephone Line "A" Profile.

STATE OF HAWAII
DEPARTMENT OF TRANSPORTATION
HIGHWAYS DIVISION

UTILITIES PROFILES

FORT WEAVER ROAD
SOUTH OF FARRINGTON HIGHWAY
TO THE VICINITY OF RENTON ROAD


SCALE: HORIZ.: 1"=50'
VERTICAL: 1"=10'

DATE: SEPT 1979


SHEET No. 70 OF 80 SHEETS

DATE	REVISION
11/9/81	Added Missing Duct Window at Manhole No. 2. Added Cardinal Point Designations to each Manhole Detail.


FED. ROAD DIST. NO.	STATE	FED. AID PROJ. NO.	FISCAL YEAR	SHEET NO.	TOTAL SHEETS
HAWAII	HAW.	M-7600(2)	1980	141	244

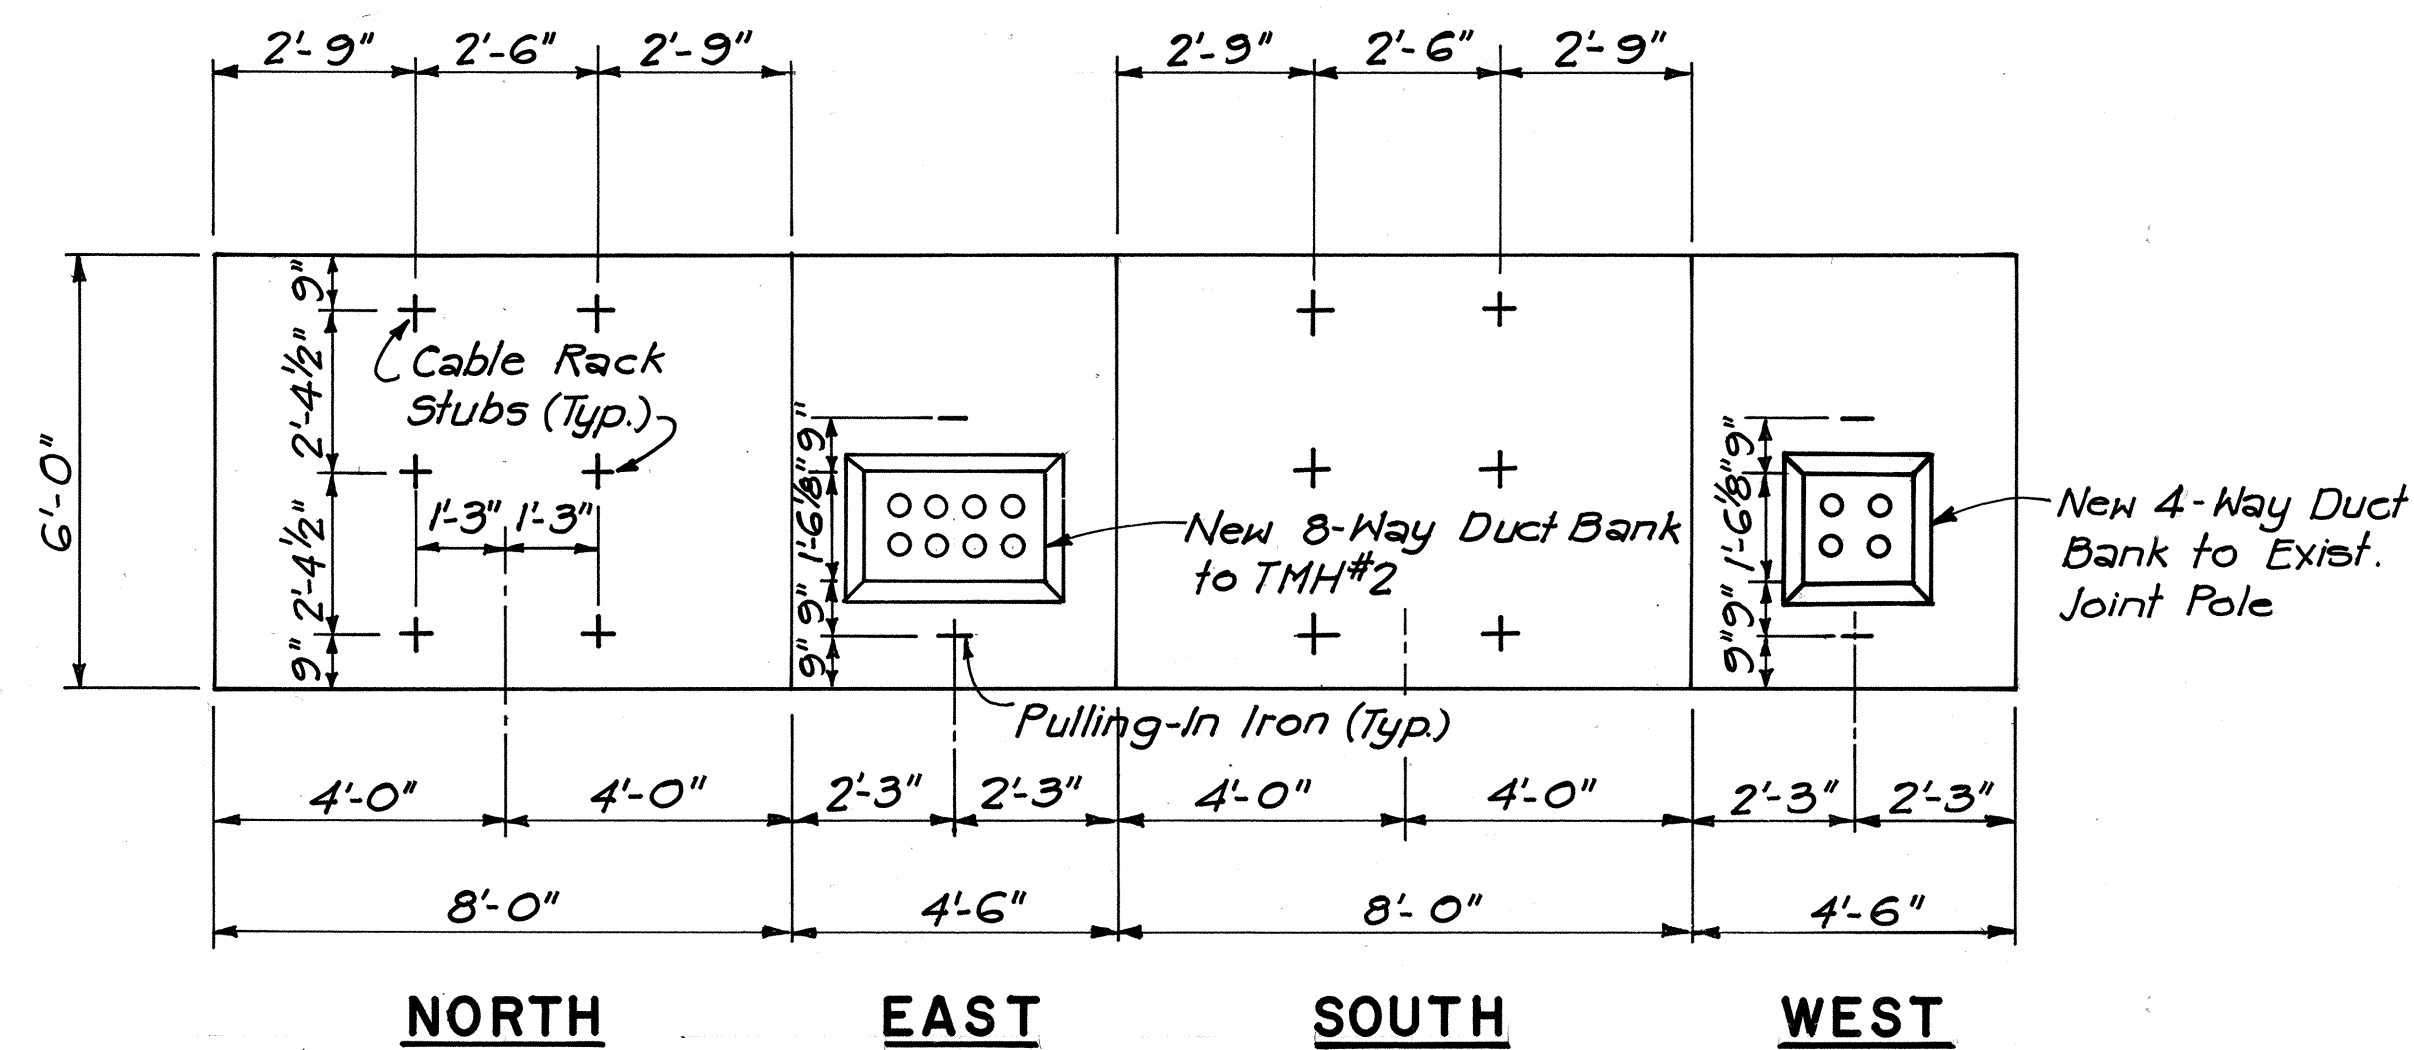


TYPE A-1-6 MANHOLE NO.1

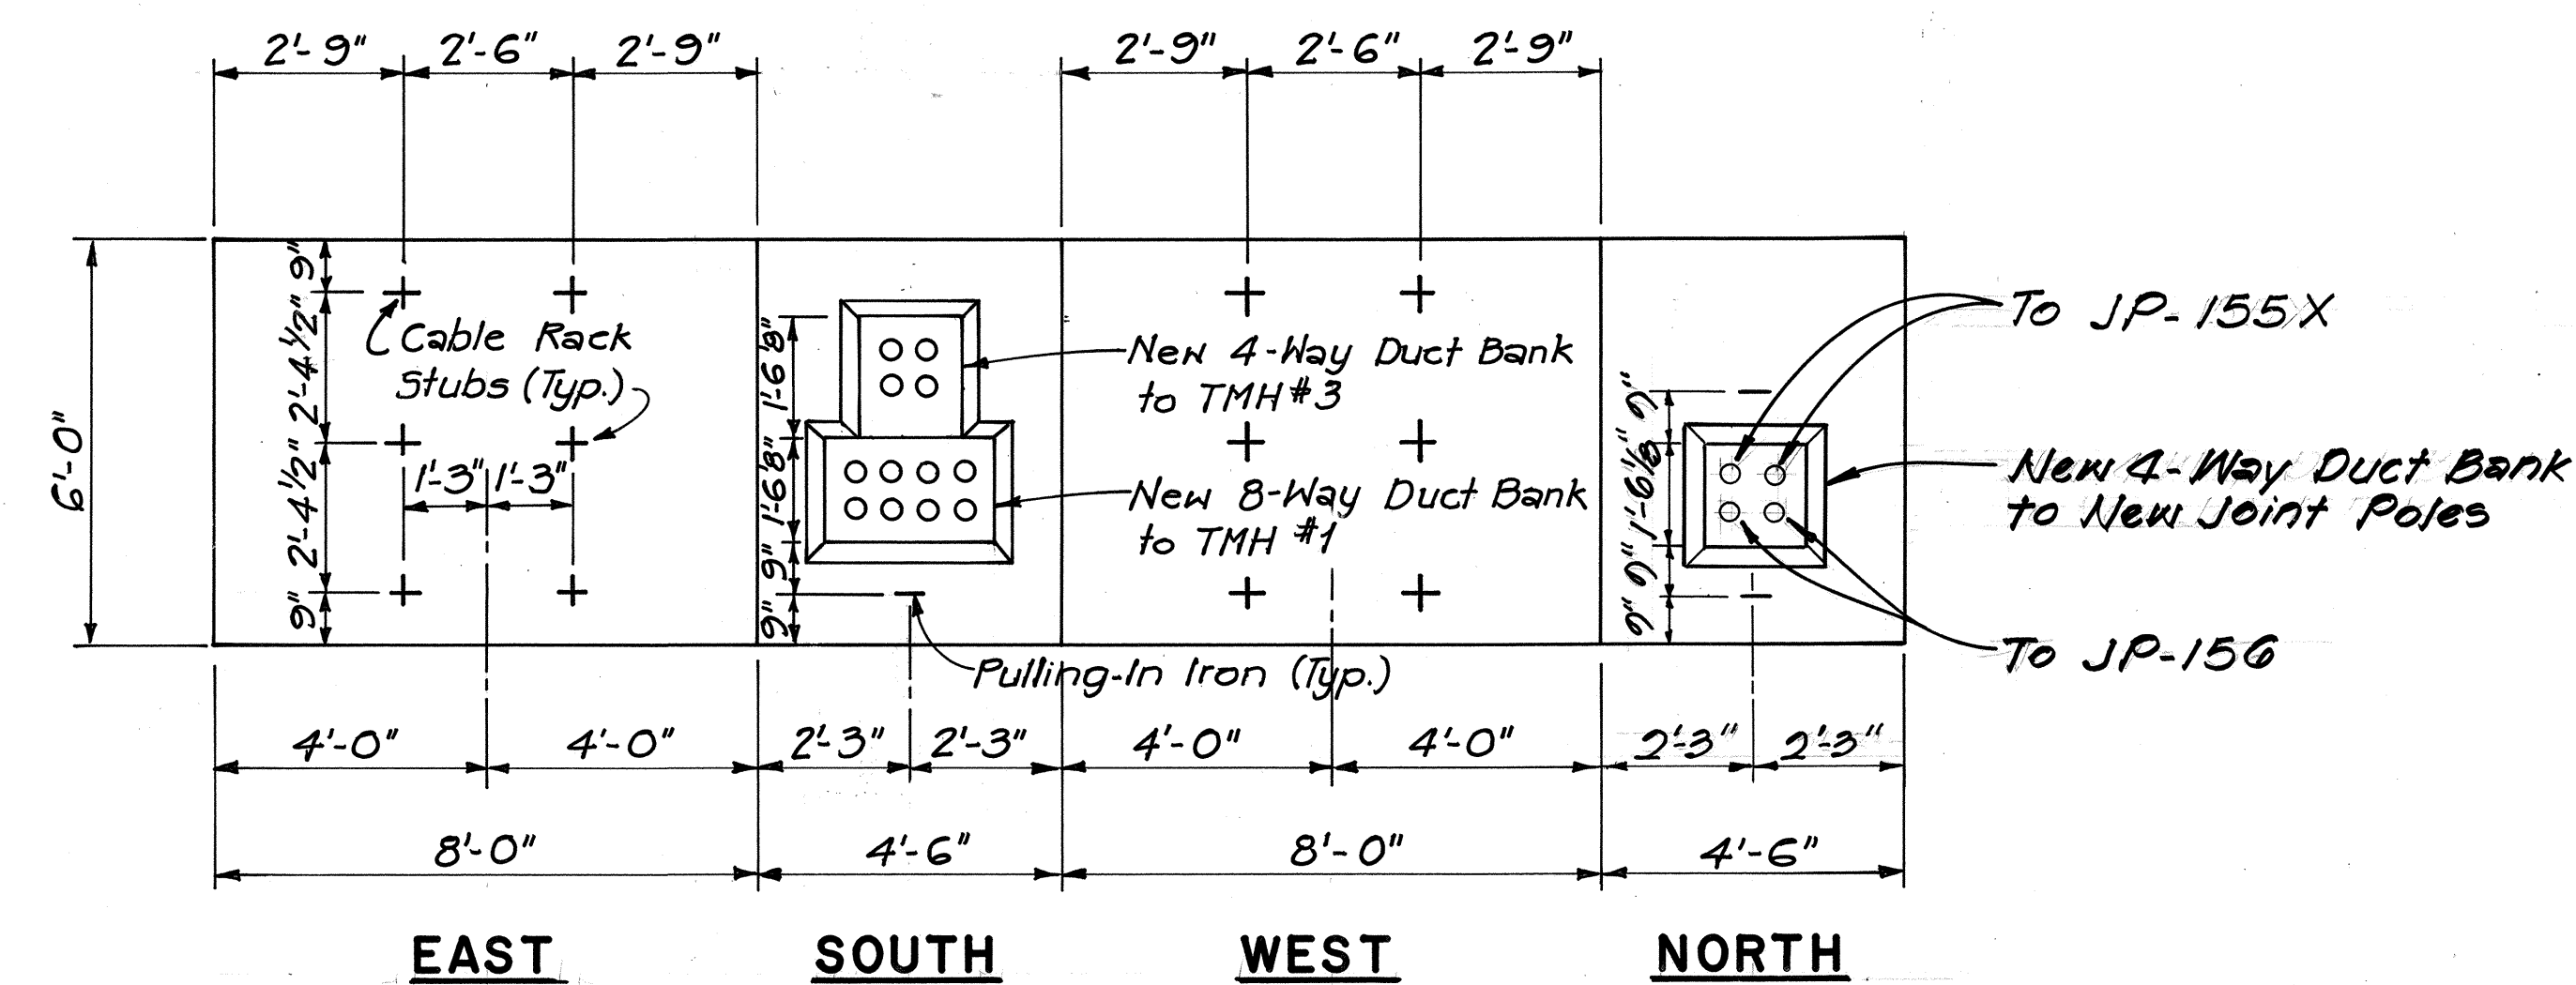

TYPE A-1-6 MANHOLE NO.2

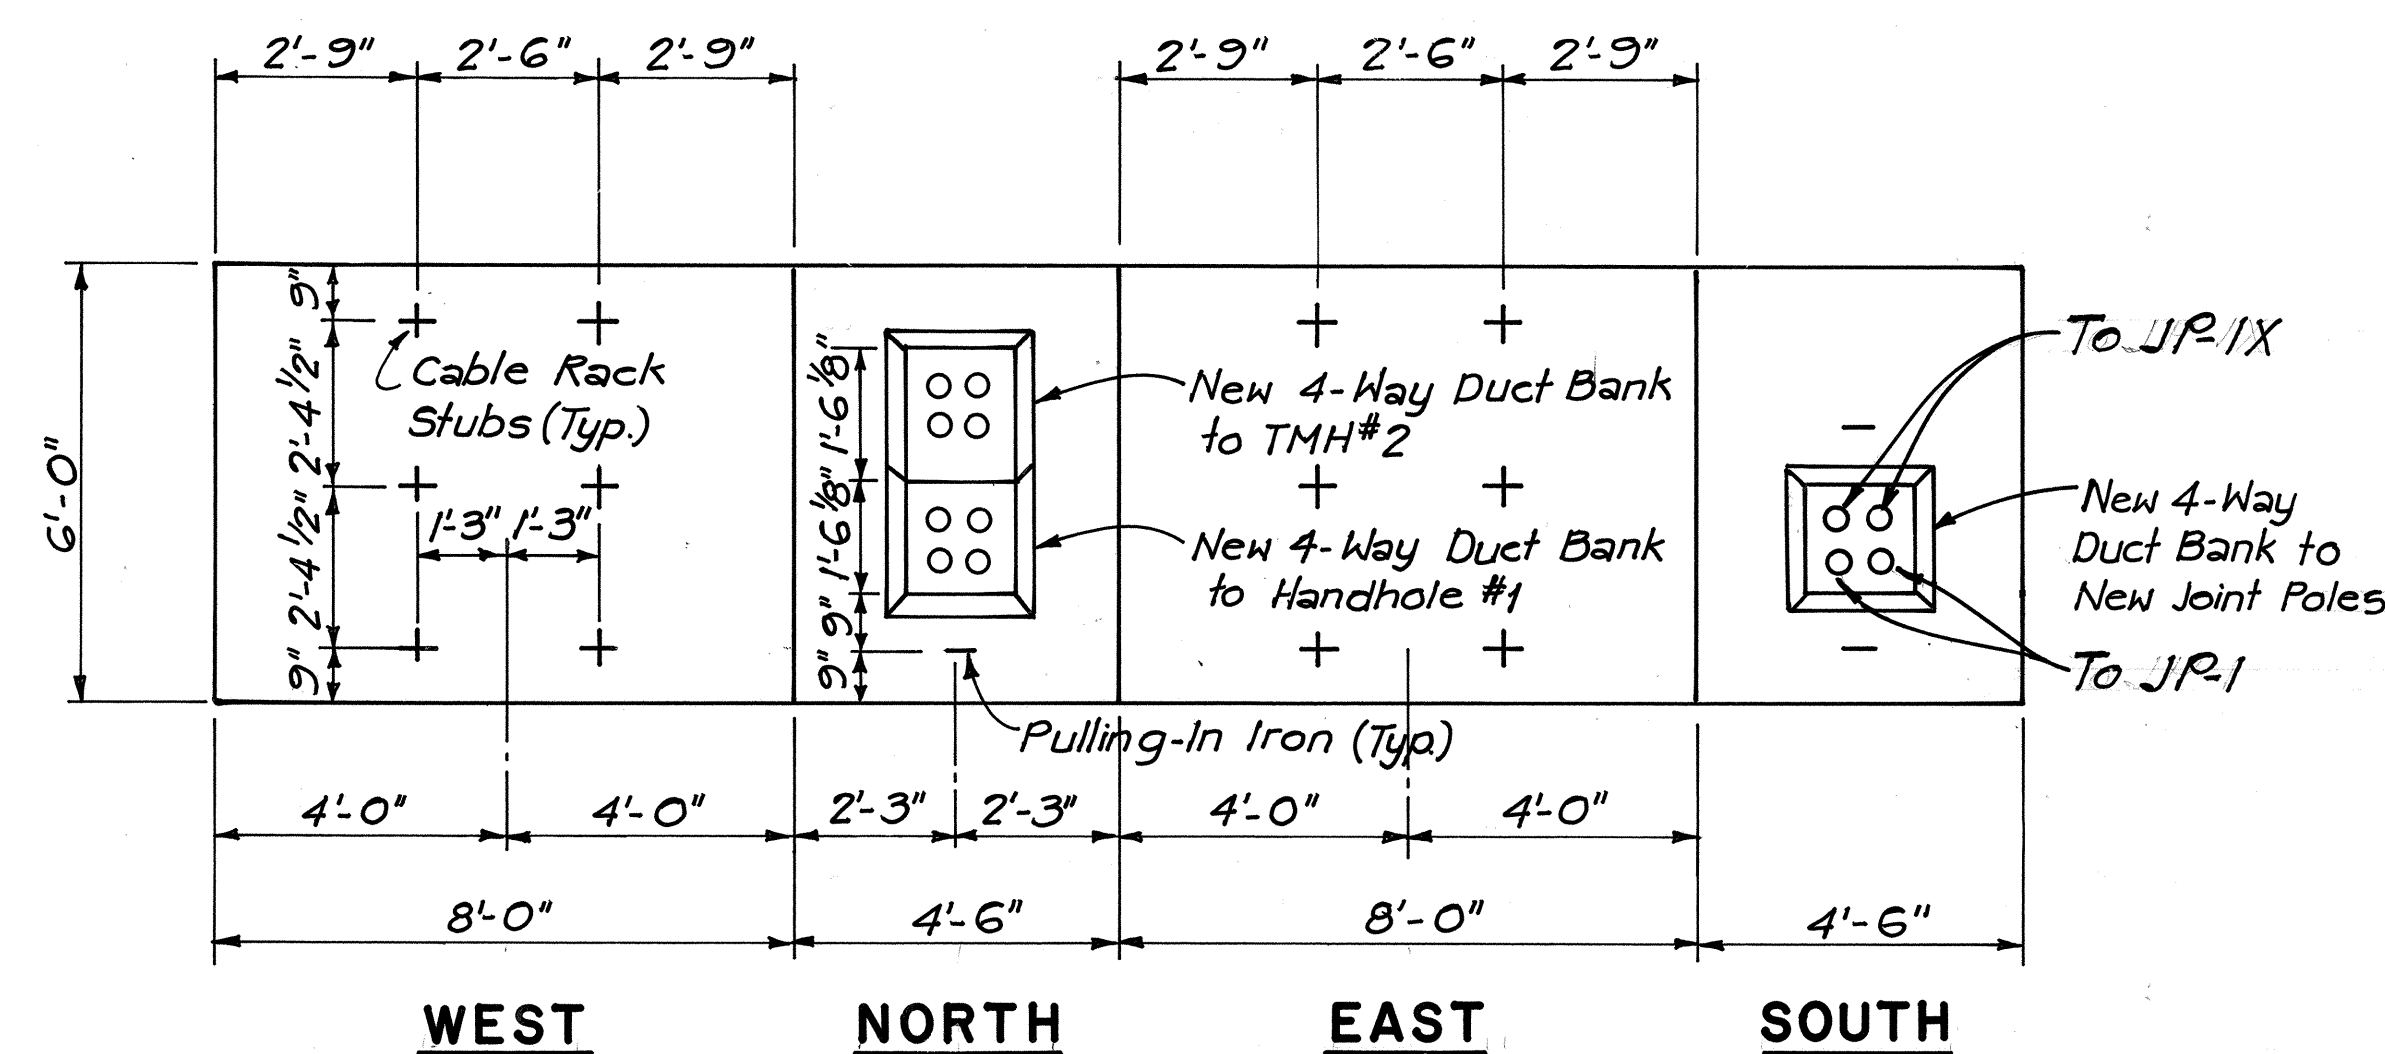

TYPE A-1-6 MANHOLE NO.3

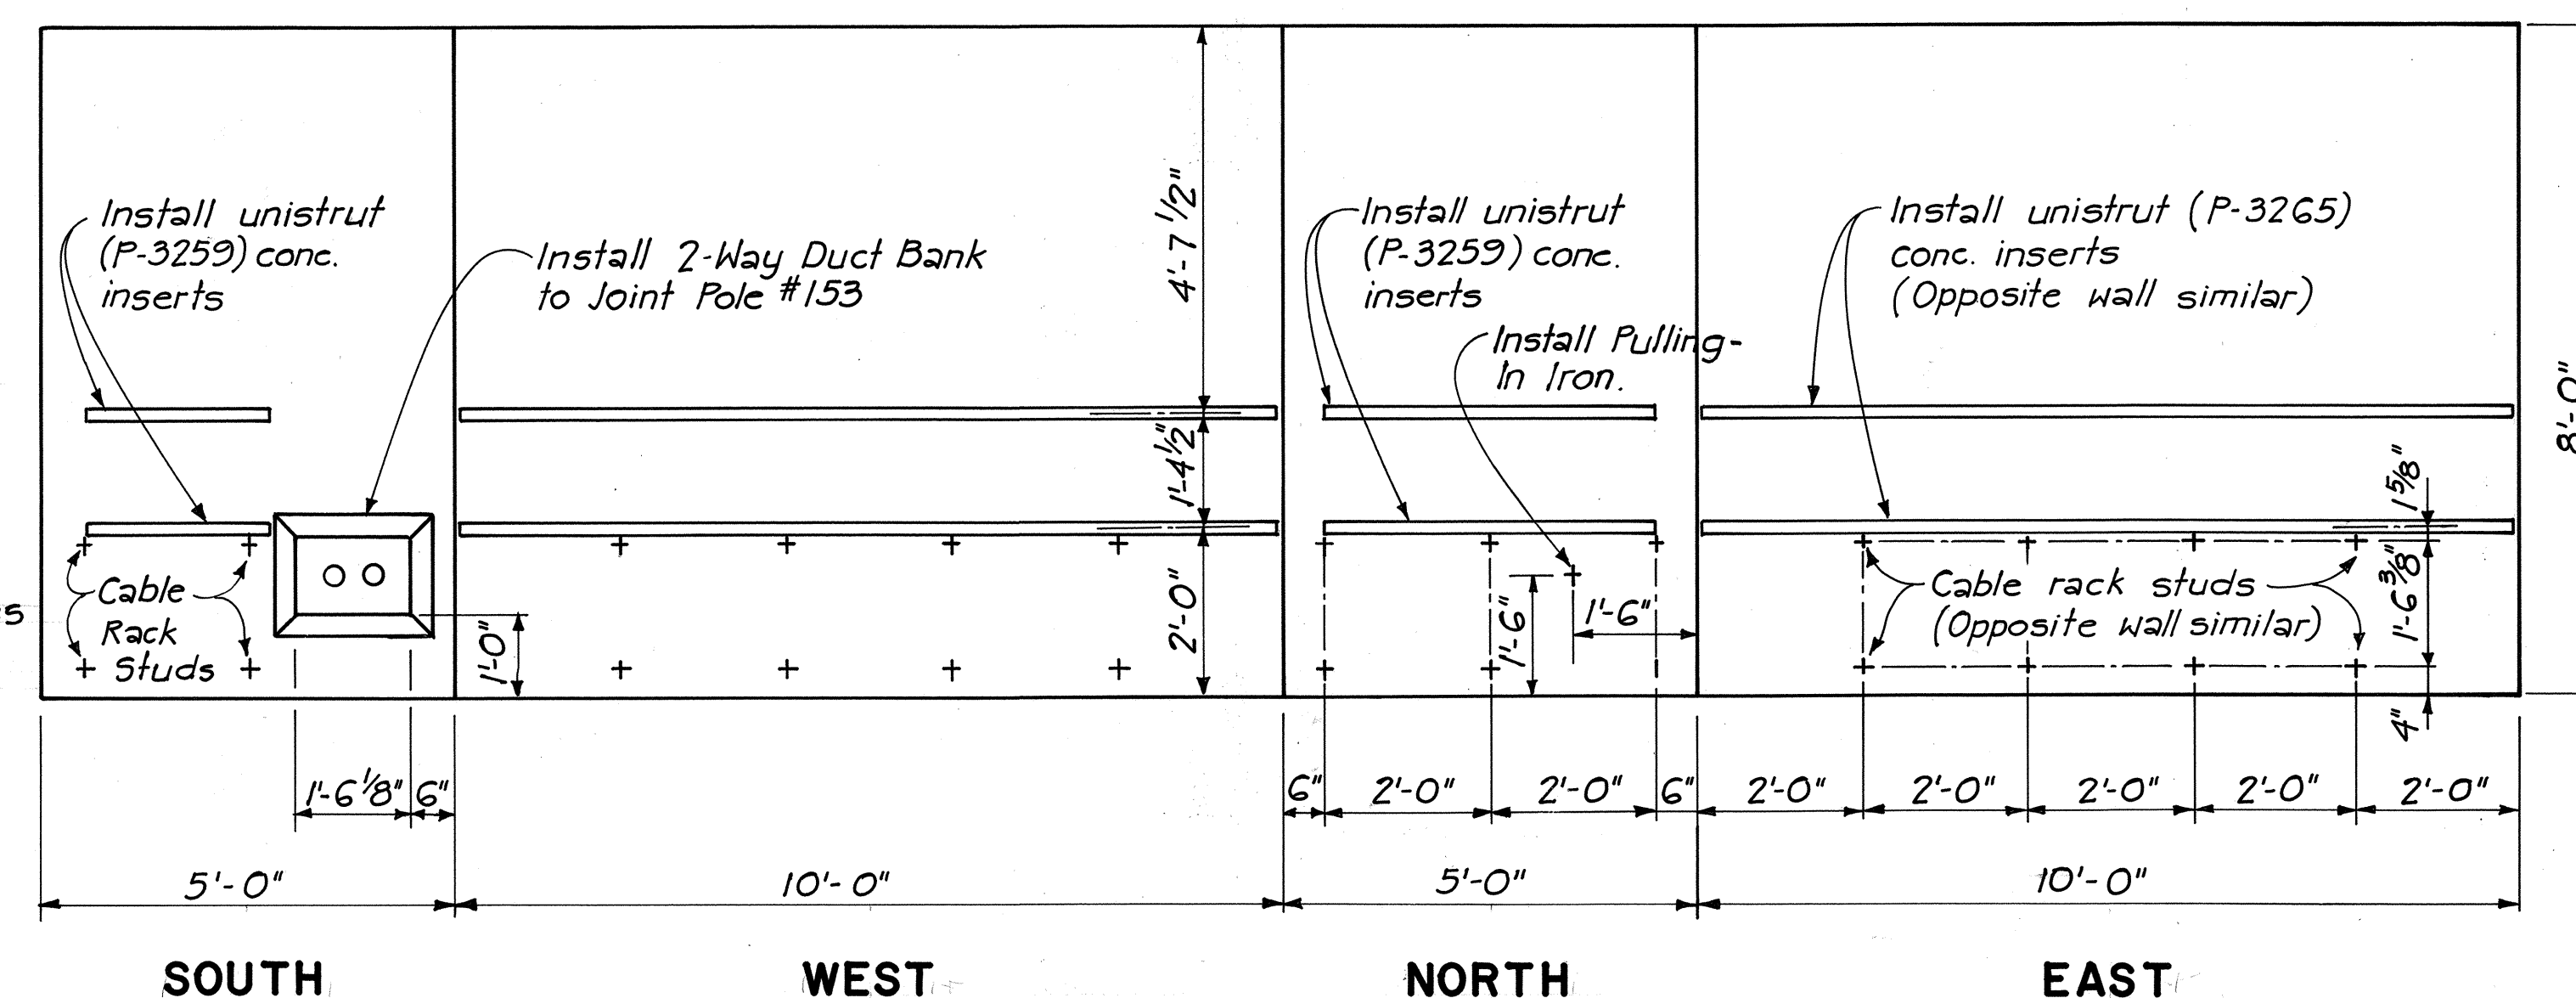


TYPE A-3-8 MANHOLE

SURVEY PLOTTED BY	DATE
DRAWN BY	
DESIGNED BY	
QUANTITIES BY	
CHECKED BY	

Sefamala
Hawaiian Telephone Co.

11-8-79
Date

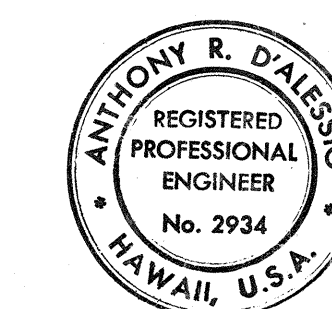

THIS WORK WAS PREPARED BY
ME OR UNDER MY SUPERVISION.
[Signature]

STATE OF HAWAII
DEPARTMENT OF TRANSPORTATION
LAND TRANSPORTATION FACILITIES DIVISION

**MANHOLE WALL
ELEVATIONS - TELEPHONE**


FORT WEAVER ROAD
SOUTH OF FARRINGTON HIGHWAY
TO THE VICINITY OF RENTON ROAD

DATE: SEPT 1979


SHEET NO. 8U OF 8U SHEETS

C0 141


FED. ROAD DIST. NO.	STATE	FED. AID PROJ. NO.	FISCAL YEAR	SHEET NO.	TOTAL SHEETS
HAWAII	HAW.	M-7600(2)	1980	142	244

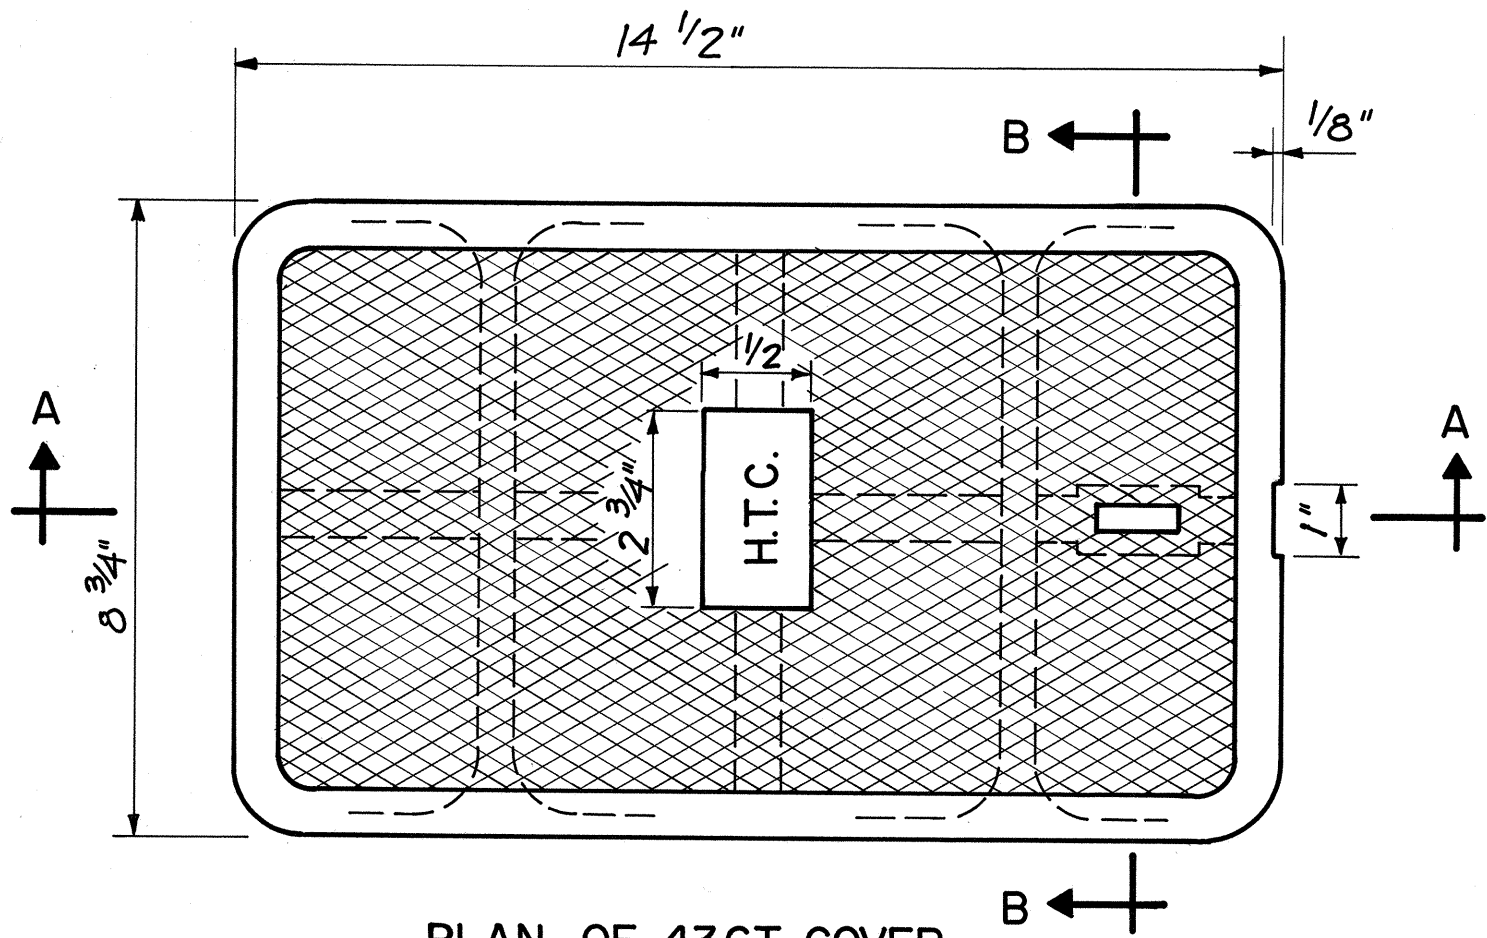


PLAN OF 436T COVER
WT = 17 LBS
Scale : 3/8" = 1"

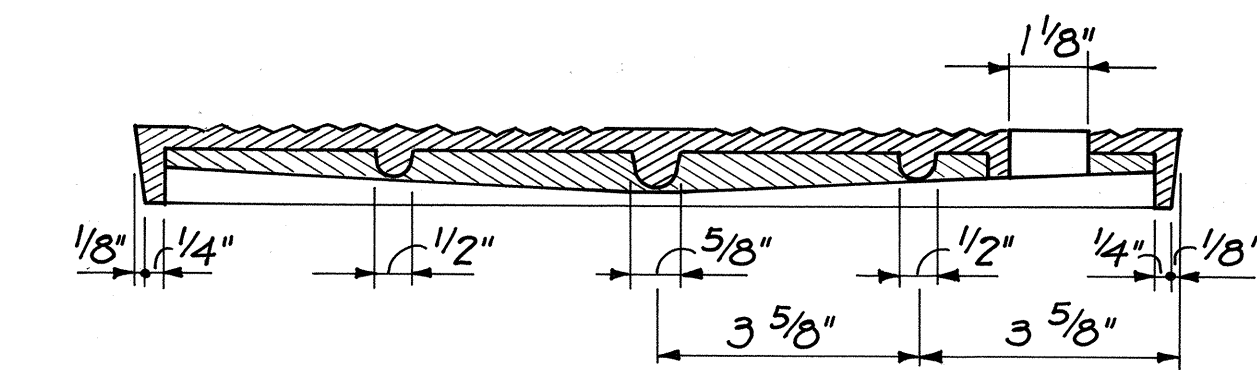

SECTION "A-A"
Scale : 3/8" = 1"

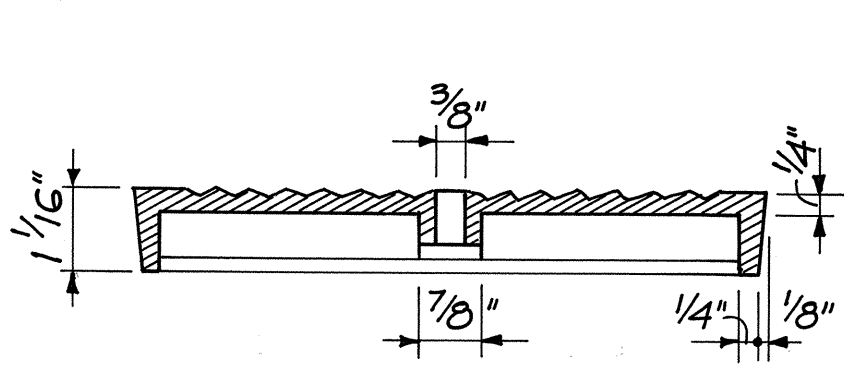

SECTION "B-B"
Scale : 3/8" = 1"



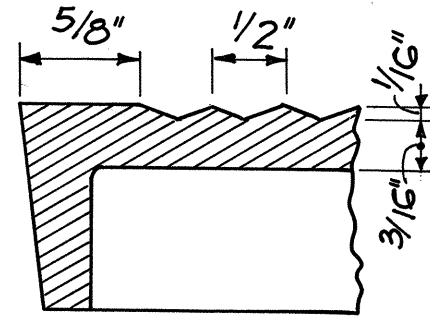


CHECKERED PATTERN


NOTES

Thickness dimensions are net.
Add 1/8" for raised surface. Use 1" high
vertical letters. Meter Cover shall be
Gray Cast Iron, free of blister, blowholes,
warpage and cold shuts.

436T PULLBOX COVER
CAST IRON

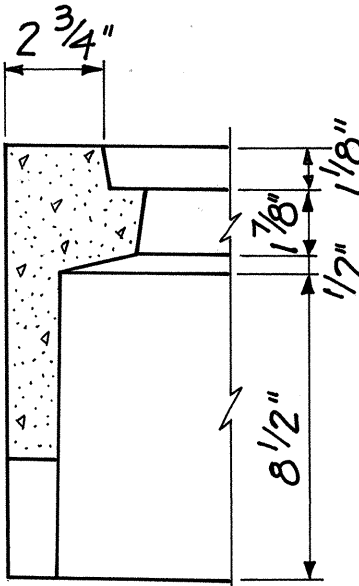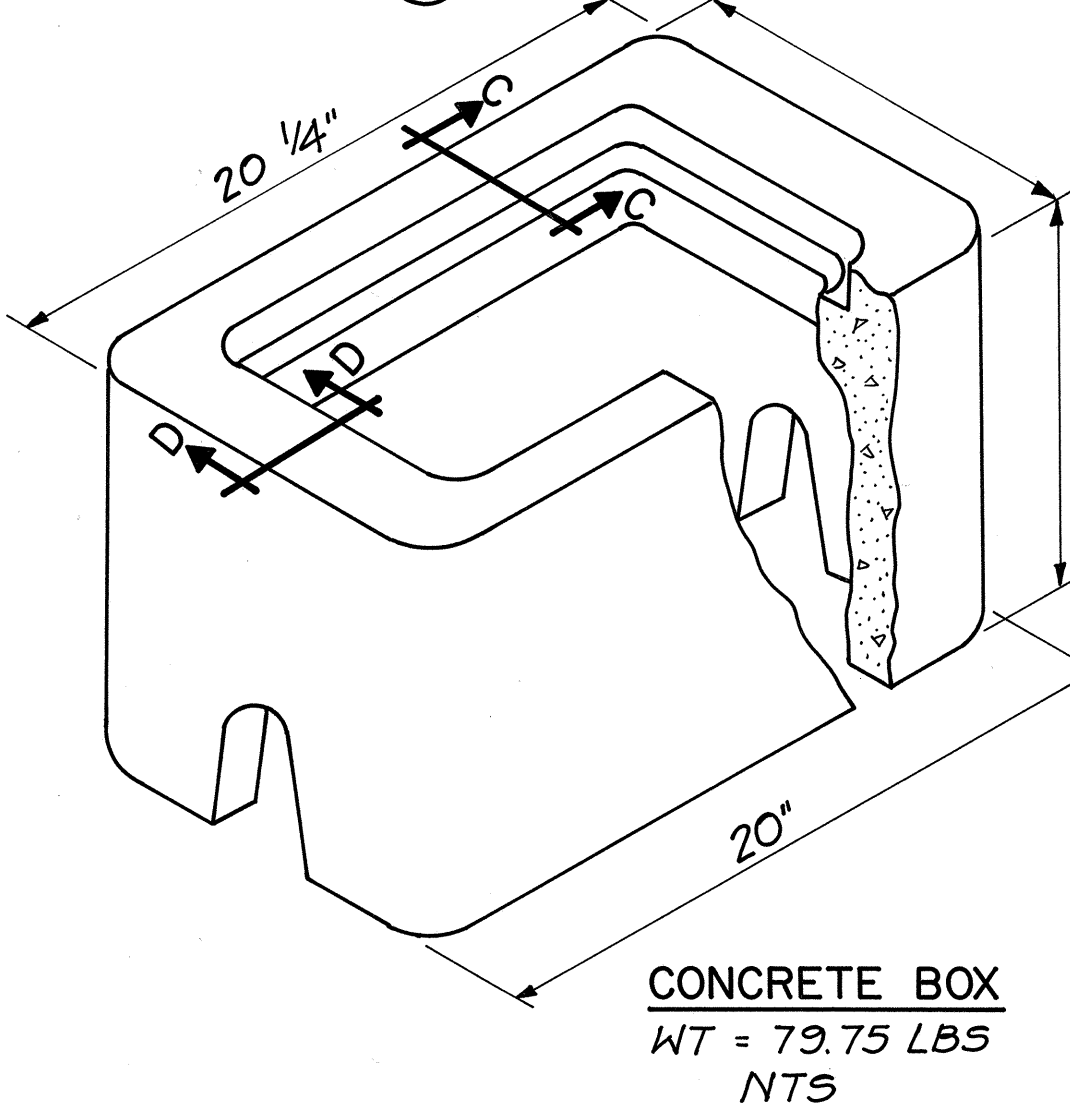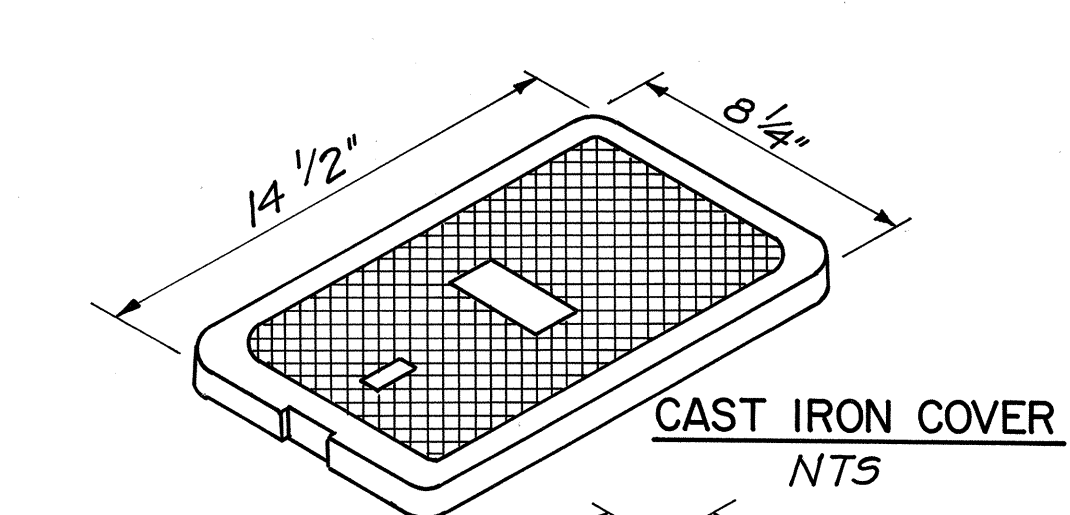


SECTION "C-C"
Scale : 3/16" = 1"

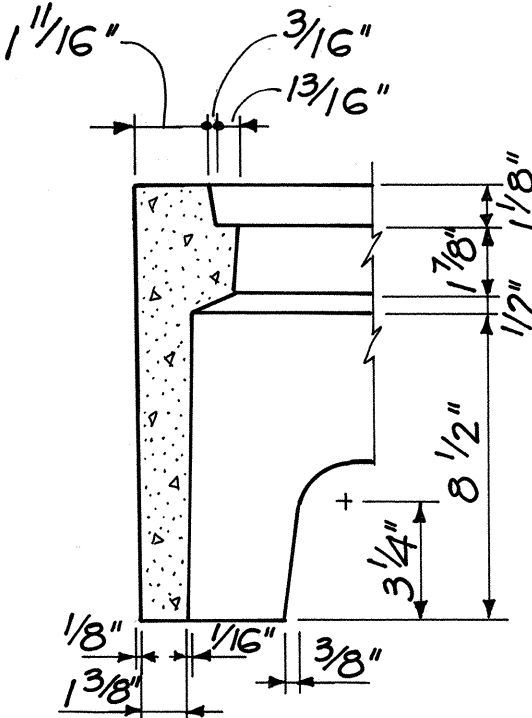

SECTION "D-D"
Scale : 3/16" = 1"

436T METER-TYPE PULLBOX

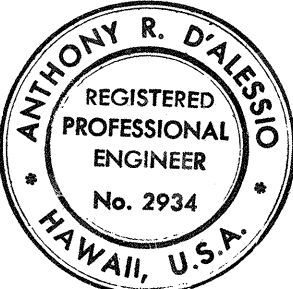

THIS WORK WAS PREPARED BY
ME OR UNDER MY SUPERVISION.
[Signature]

[Signature]
Hawaiian Telephone Co.

11-8-79
Date

STATE OF HAWAII
DEPARTMENT OF TRANSPORTATION
LAND TRANSPORTATION FACILITIES DIVISION

PULLBOX - TYPE 436T

FORT WEAVER ROAD
SOUTH OF FARRINGTON HIGHWAY
TO THE VICINITY OF RENTON ROAD

DATE : SEPT 1979

SHEET NO. 1 OF 1 SHEETS

FOR 25', & 30' POLES WITH 8'-0" ANCHOR RODS				
"A"	"B"	"C"		"D" = ("A" + "B")
ANCHOR ROD EYE TO C OF POLE	ANCHOR ROD EYE TO C OF HOLE	VERTICAL DEPTH 18" D.M.	24" D.M.	TOTAL DISTANCE POLE TO HOLE
5' - 0"	1' - 8"	7' - 1"	7' - 4"	6' - 8"
10' - 0"	3' - 0"	6' - 7"	7' - 0"	13' - 0"
15' - 0"	4' - 0"	6' - 1"	6' - 6"	19' - 0"
20' - 0"	4' - 8"	5' - 6"	5' - 10"	24' - 8"
25' - 0"	5' - 2"	4' - 11"	5' - 4"	30' - 2"
FOR 35' THRU 60' POLES WITH 8'-0" ANCHOR RODS				
5' - 0"	1' - 0"	7' - 3"	7' - 4"	6' - 0"
10' - 0"	1' - 11"	7' - 1"	7' - 3"	11' - 11"
15' - 0"	2' - 8"	6' - 9"	7' - 1"	17' - 8"
20' - 0"	3' - 3"	6' - 6"	6' - 10"	23' - 3"
25' - 0"	3' - 10"	6' - 2"	6' - 7"	28' - 10"
FOR 40' THRU 60' POLES WITH 1 1/4" x 10'-0" ANCHOR RODS				
5' - 0"	1' - 7"		9' - 4"	6' - 7"
10' - 0"	3' - 0"		9' - 0"	13' - 0"
15' - 0"	4' - 2"		8' - 6"	19' - 2"
20' - 0"	5' - 3"		7' - 11"	25' - 3"
25' - 0"	6' - 2"		7' - 3"	31' - 2"

D.M. = Deadman

TABLE 2 ANCHOR ROD - ANCHOR SLUG - SQUARE WASHER COMBINATION

CODE NO.	ANCHOR ROD	WORKING TENSION 1/2 ULT (LBS.)	CODE NO.	CONC. ANC. (IN.)	CODE NO.	WASHER SIZE	QTY.
617	5/8" x 8'-0" Steel	8,000	518	18	2320	4" x 4" x 3/16"	2
614	3/4" x 8'-0" Cu Clad	13,250	518	18	**	4" x 4" x 3/16"	2
618	3/4" x 8'-0" Steel	11,500	518	18	2330	6" x 6" x 3/8"	1
619	1" x 8'-0" Steel	18,000	524	24	2331	6" x 6" x 1/2"	1
616	1" x 8'-0" Cu Cov Stl	22,500	524	24	**	4" x 4" x 3/16"	2
613	1-1/4" x 10'-0" Steel	29,000	524	24	2331	6" x 6" x 1/2"	2

** Use bronze square washers included in anchor rod assembly on copper covered steel (Cu Cov Stl) anchor rods.

ANCHORING DATA

APPROVED:

N/A
HAWAIIAN ELECTRIC Co., Inc. DATE

N/A
HAWAIIAN TELEPHONE Co. DATE


STATE OF HAWAII
DEPARTMENT OF TRANSPORTATION
HIGHWAYS DIVISION

STANDARD DETAILS

H.E. Co. AND H.T. Co.
ANCHOR DETAILS AND
ANCHORING DATA

Scales: As Noted Date: Mar., 1979


DD - 630.001 SHEET NO. 1 OF 8 SHEETS

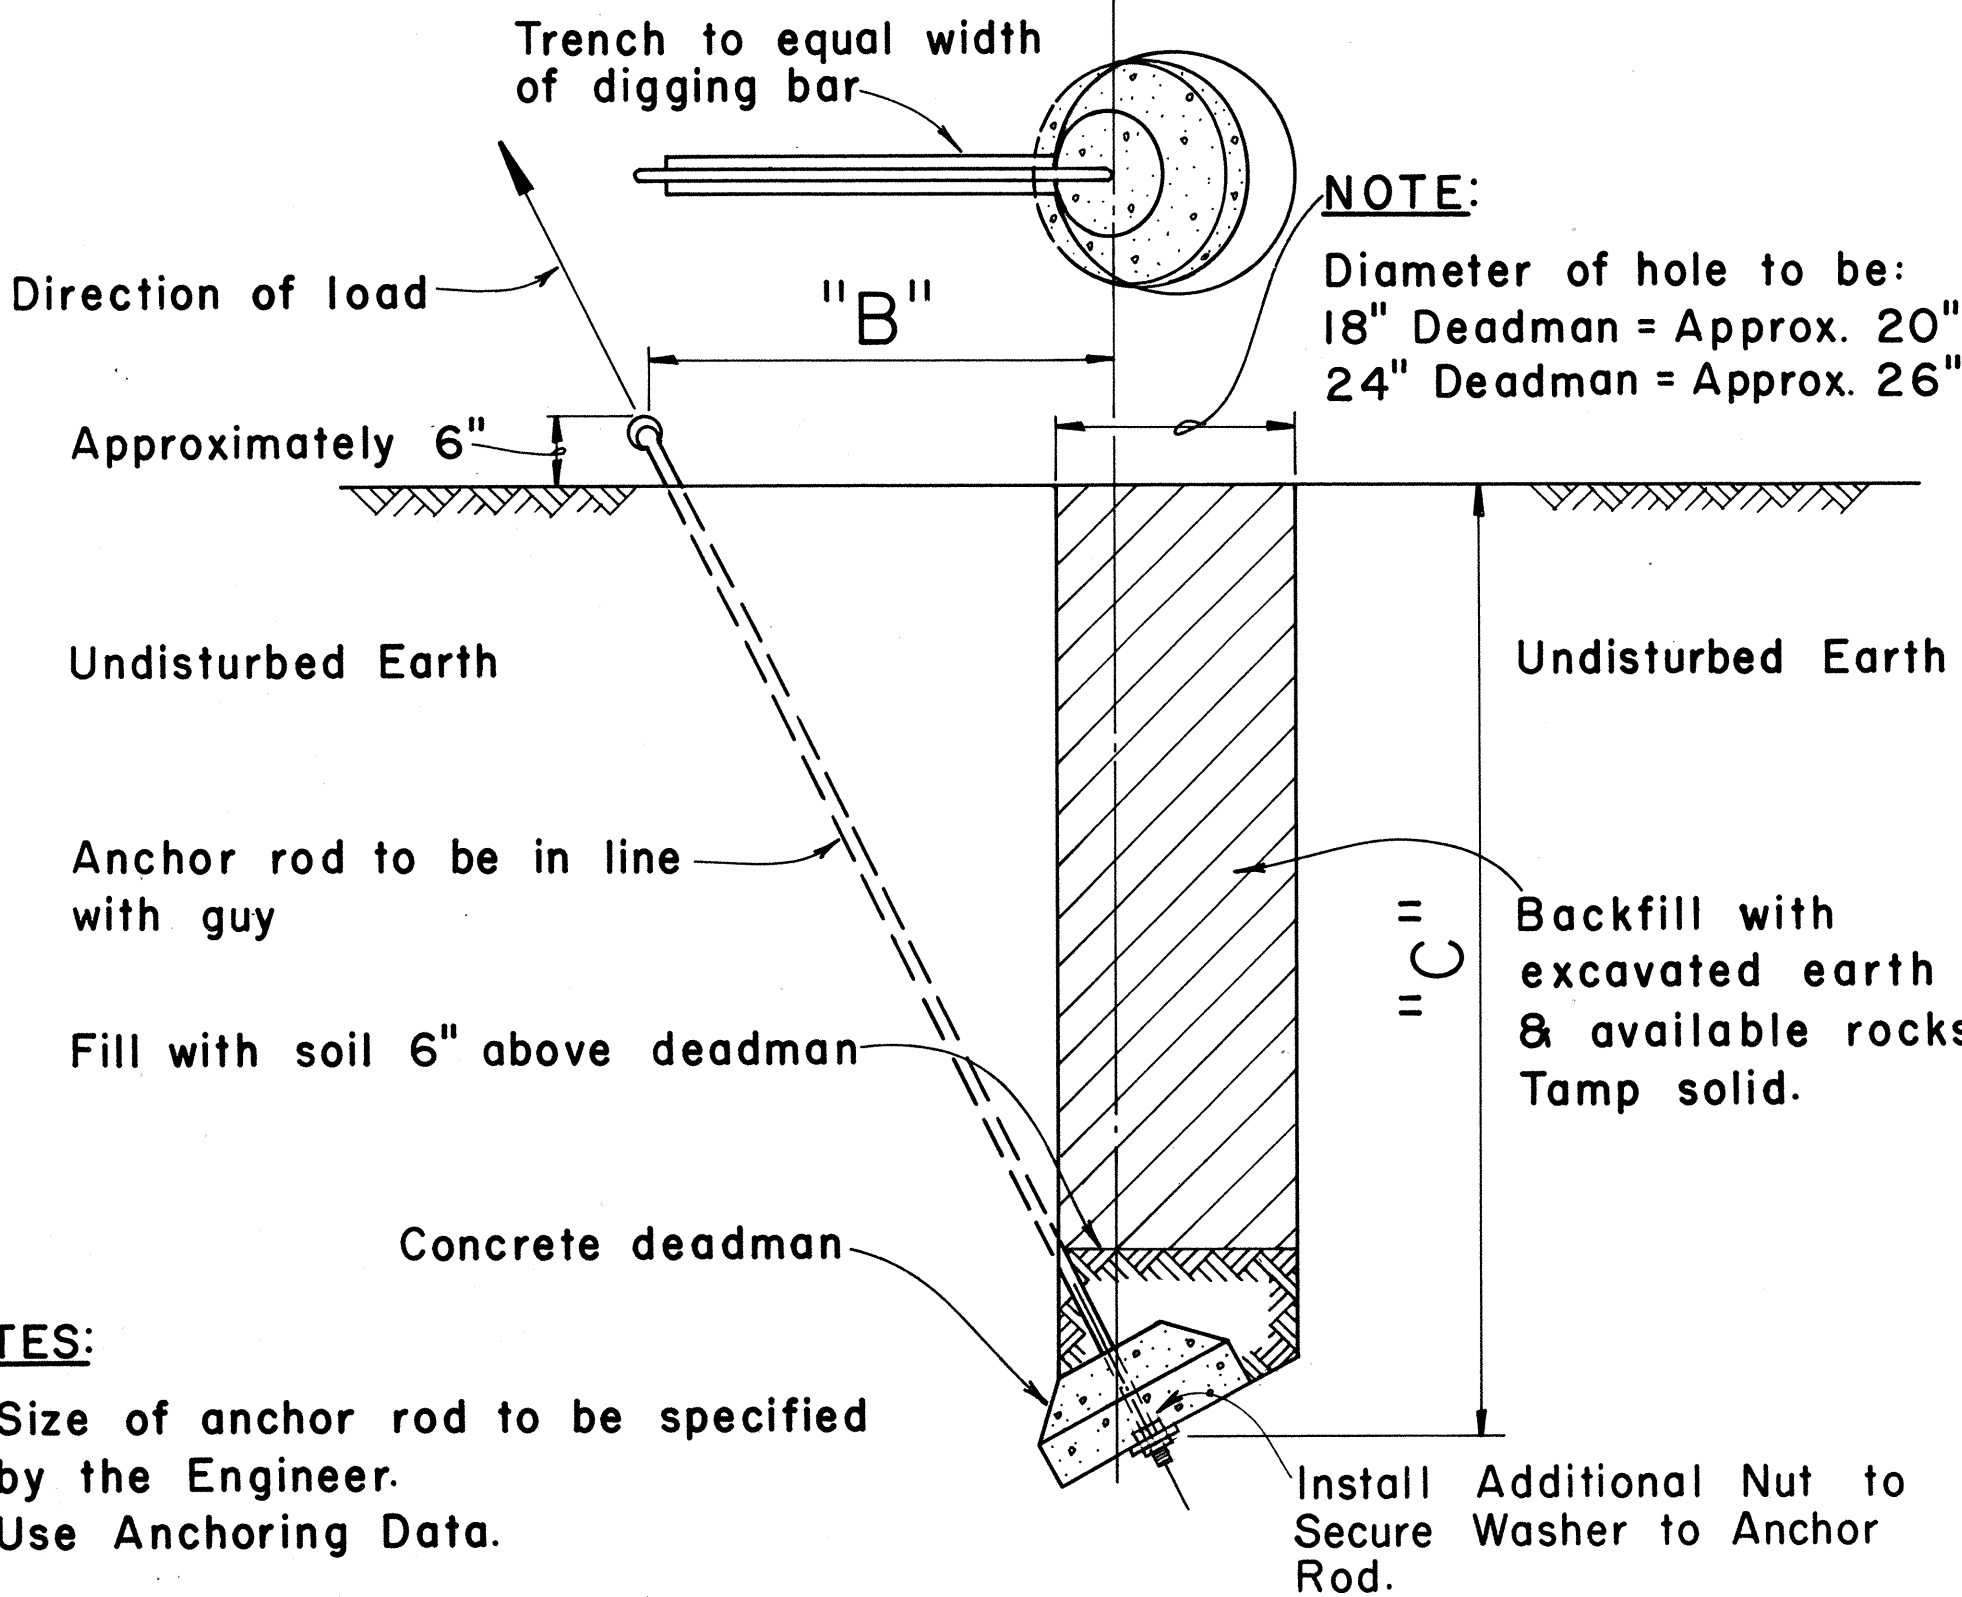

STANDARD ANCHOR DETAIL

Scale: 3/4" = 1' - 0"

- NOTES:
1. Size of anchor rod to be specified by the Engineer.
 2. Use Anchoring Data.

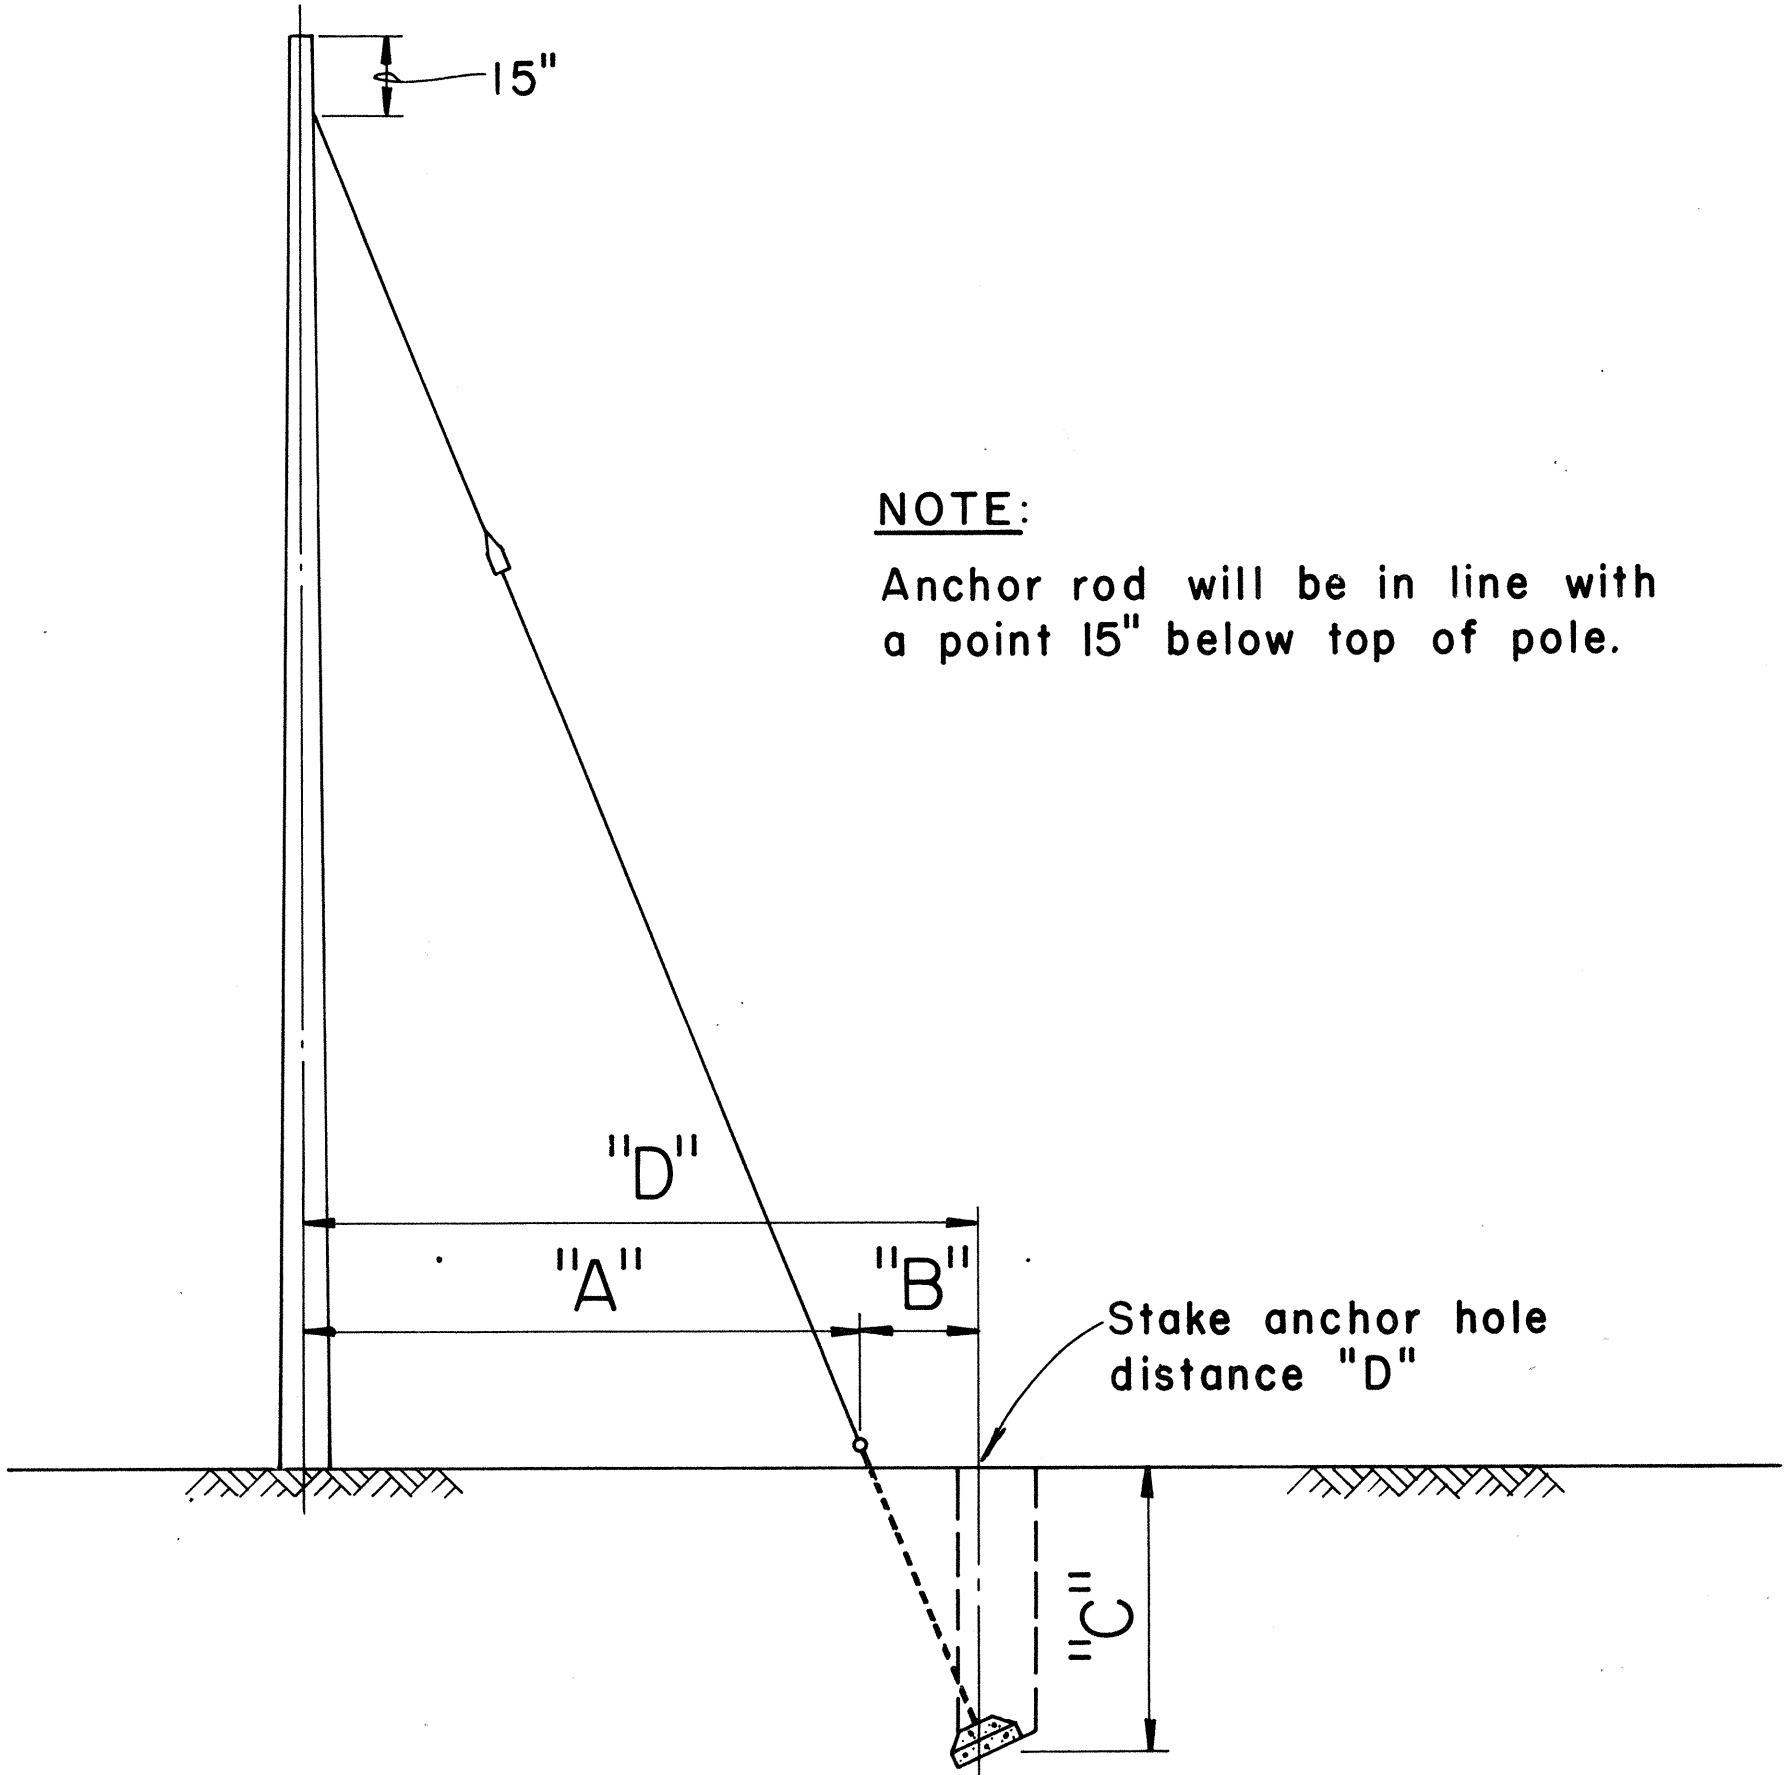


ROCK ANCHOR DETAIL

Not to Scale

NOTES:

1. Size of anchor rod to be specified by the Engineer.
2. "X" should not be less than 24". If "X" is less than 24" complete hole & install as per STANDARD / SIDEWALK DETAIL.
3. "Y" 5/8" Anchor rod drill 2" hole
3/4" Anchor rod drill 2" hole
1" Anchor rod drill 2 1/2" hole
1 1/4" Anchor rod drill 3" hole
4. Use Anchoring Data.

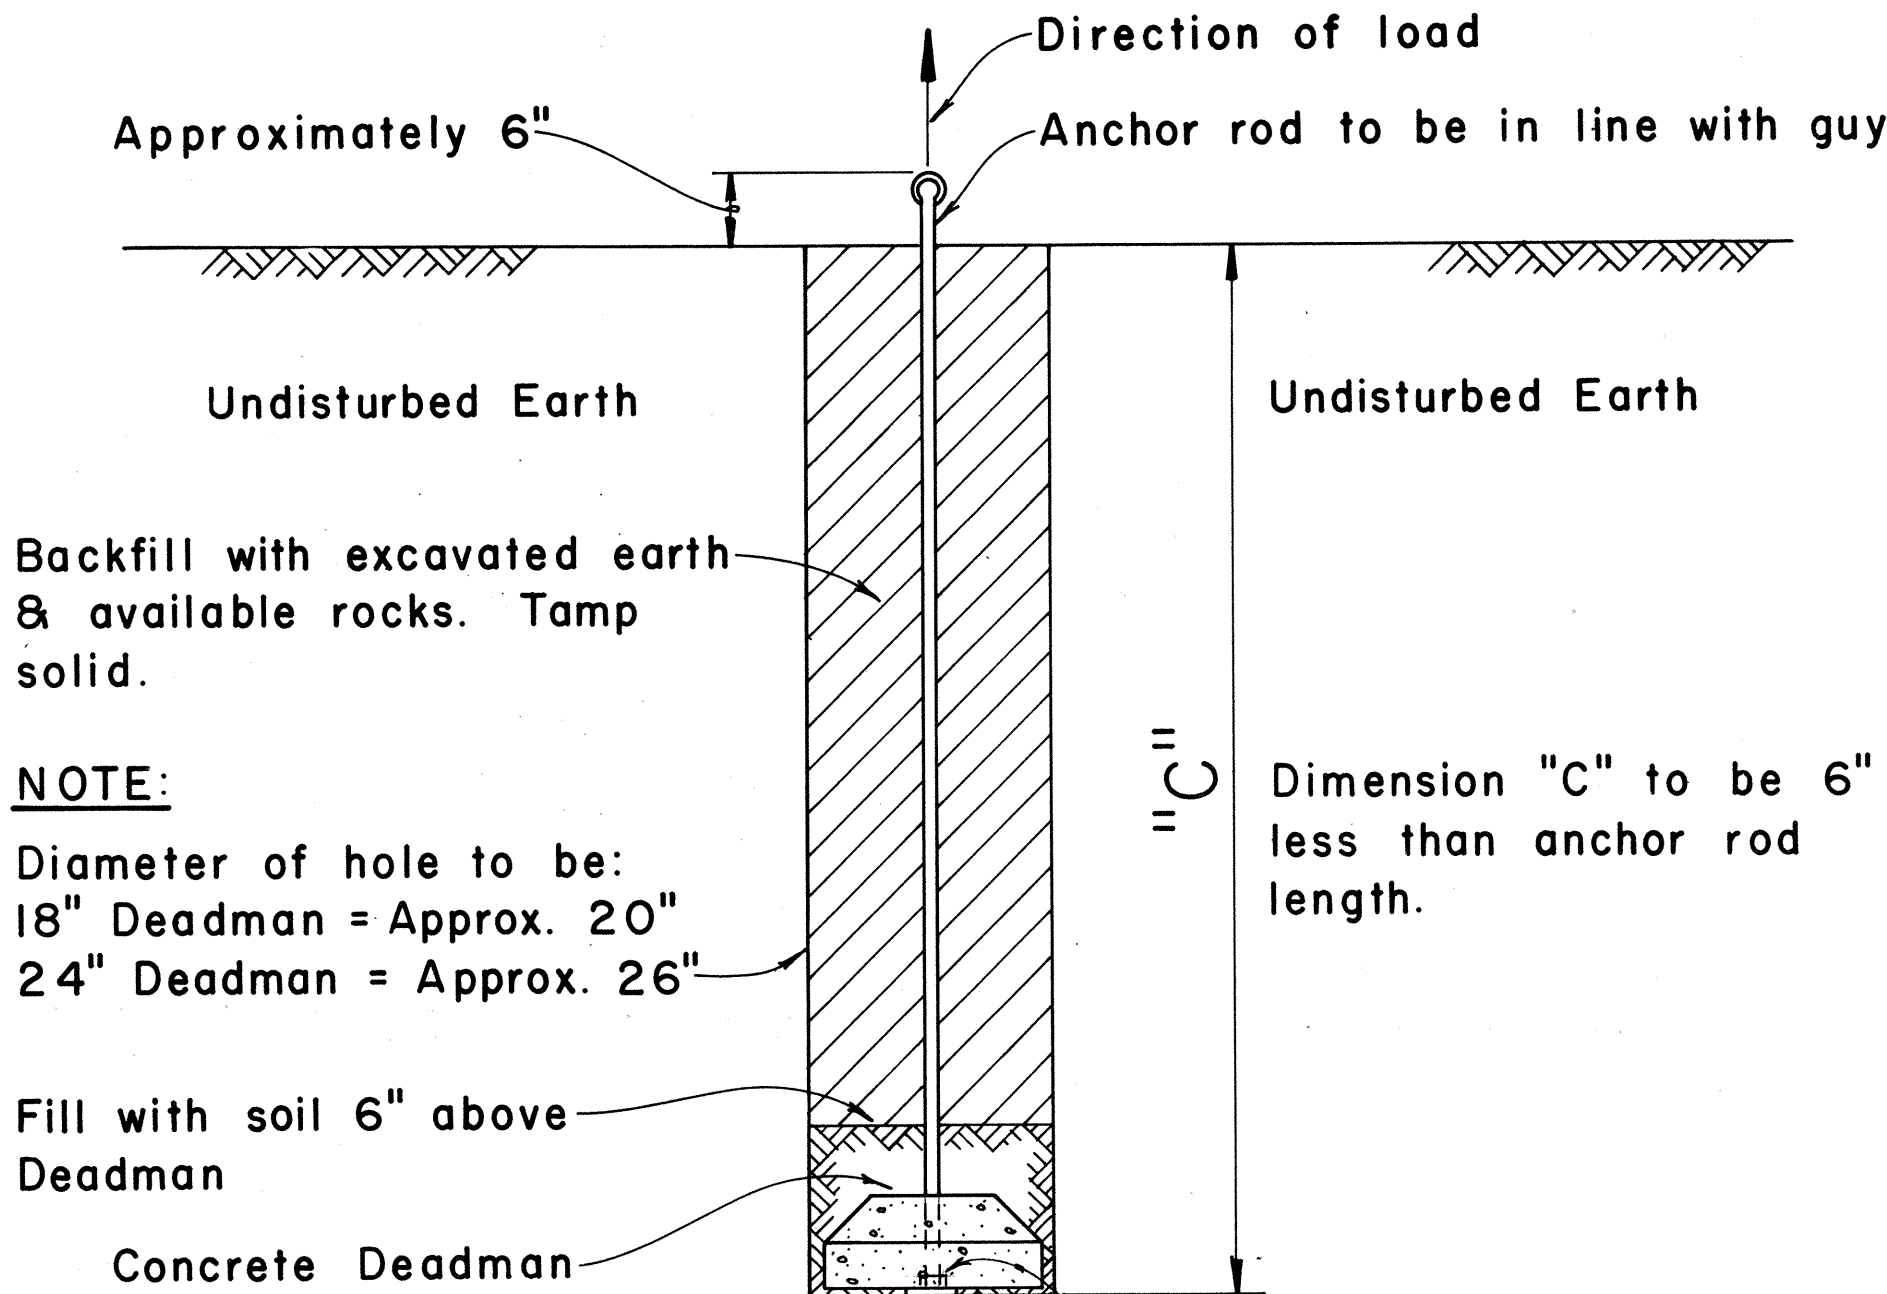




SIDEWALK ANCHOR DETAIL

Scale: 3/4" = 1' - 0"

- NOTES:
1. Size of anchor rod to be specified by the Engineer.
 2. Use Anchoring Data.

DATE: _____
SURVEY PLOTTED BY: _____
ORIGINAL PLAN: _____
DRAWN BY: _____
TRACED BY: _____
NOTE BOOK: _____
DESIGNED BY: _____
QUANTITIES BY: _____
CHECKED BY: _____
No. _____





FED. ROAD DIST. NO.	STATE	FED. AID PROJ. NO.	FISCAL YEAR	SHEET NO.	TOTAL SHEETS
HAWAII	HAW.	M-7600 (2)	1980	144	244

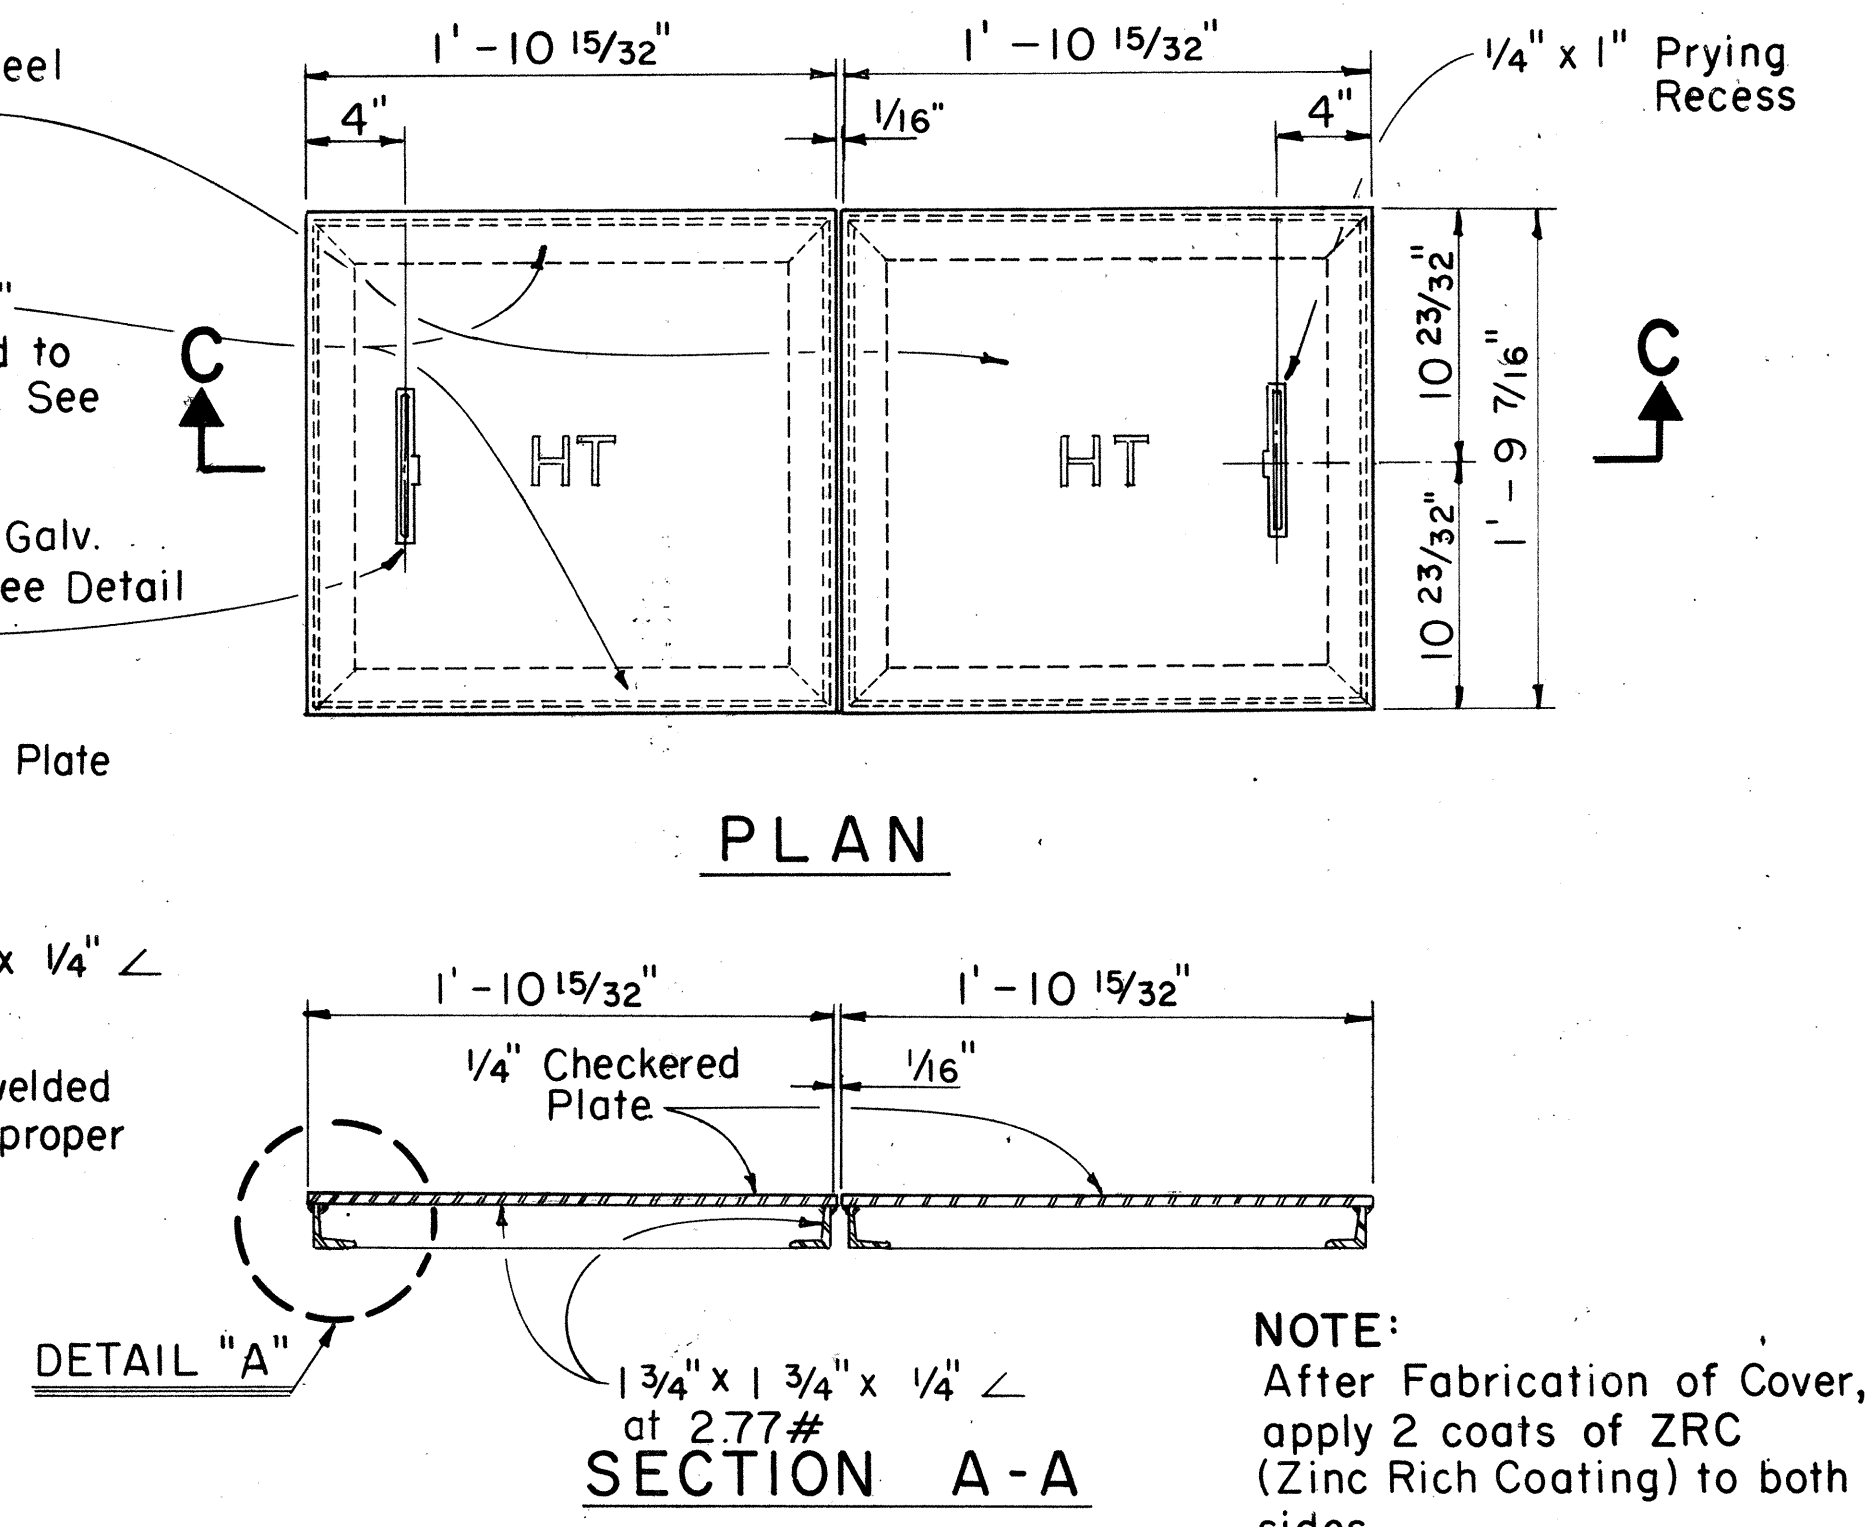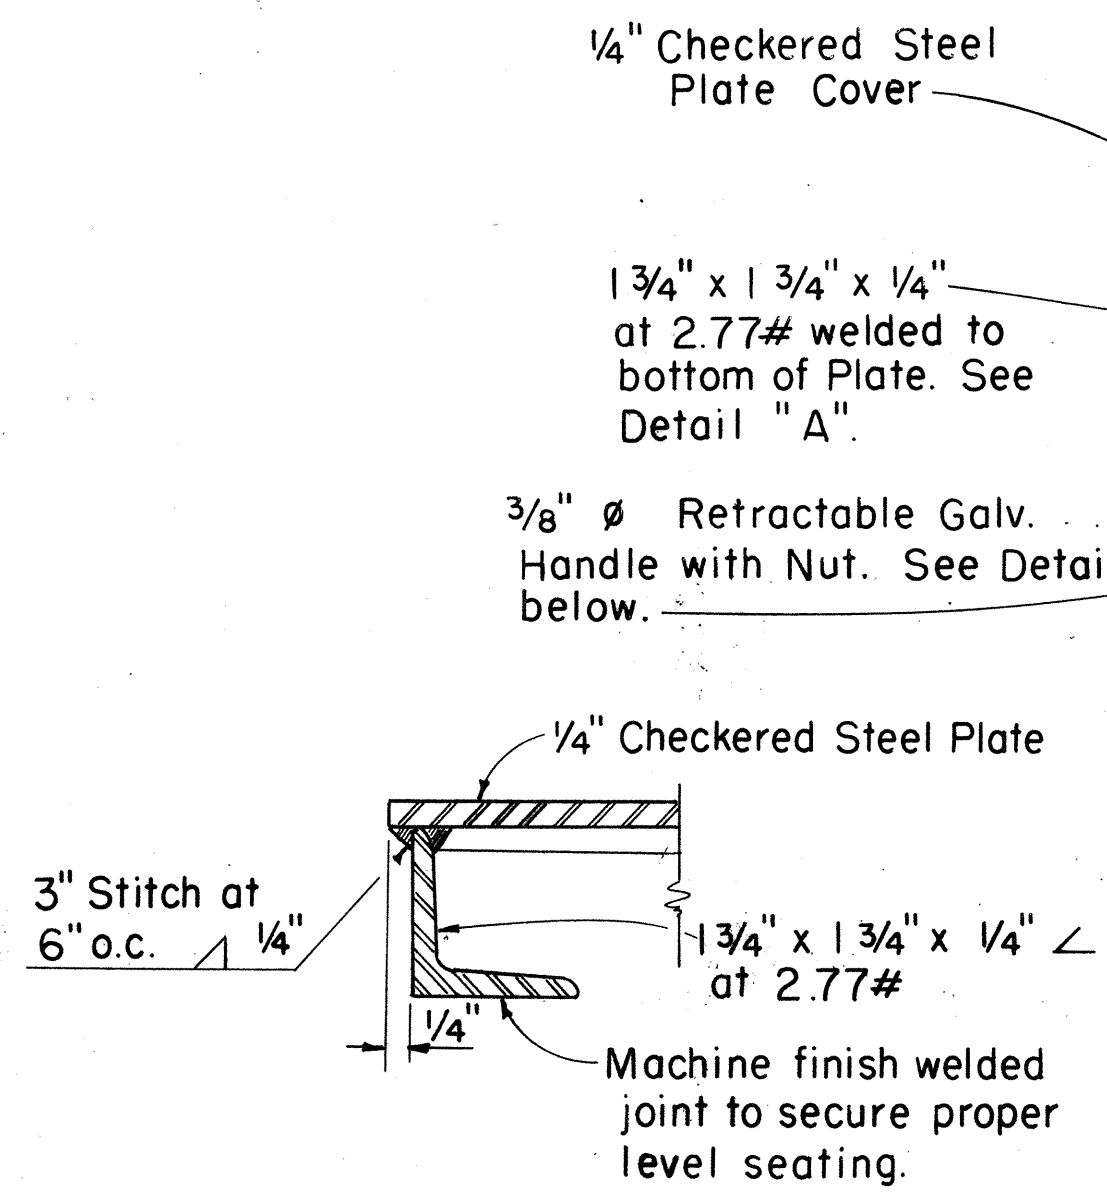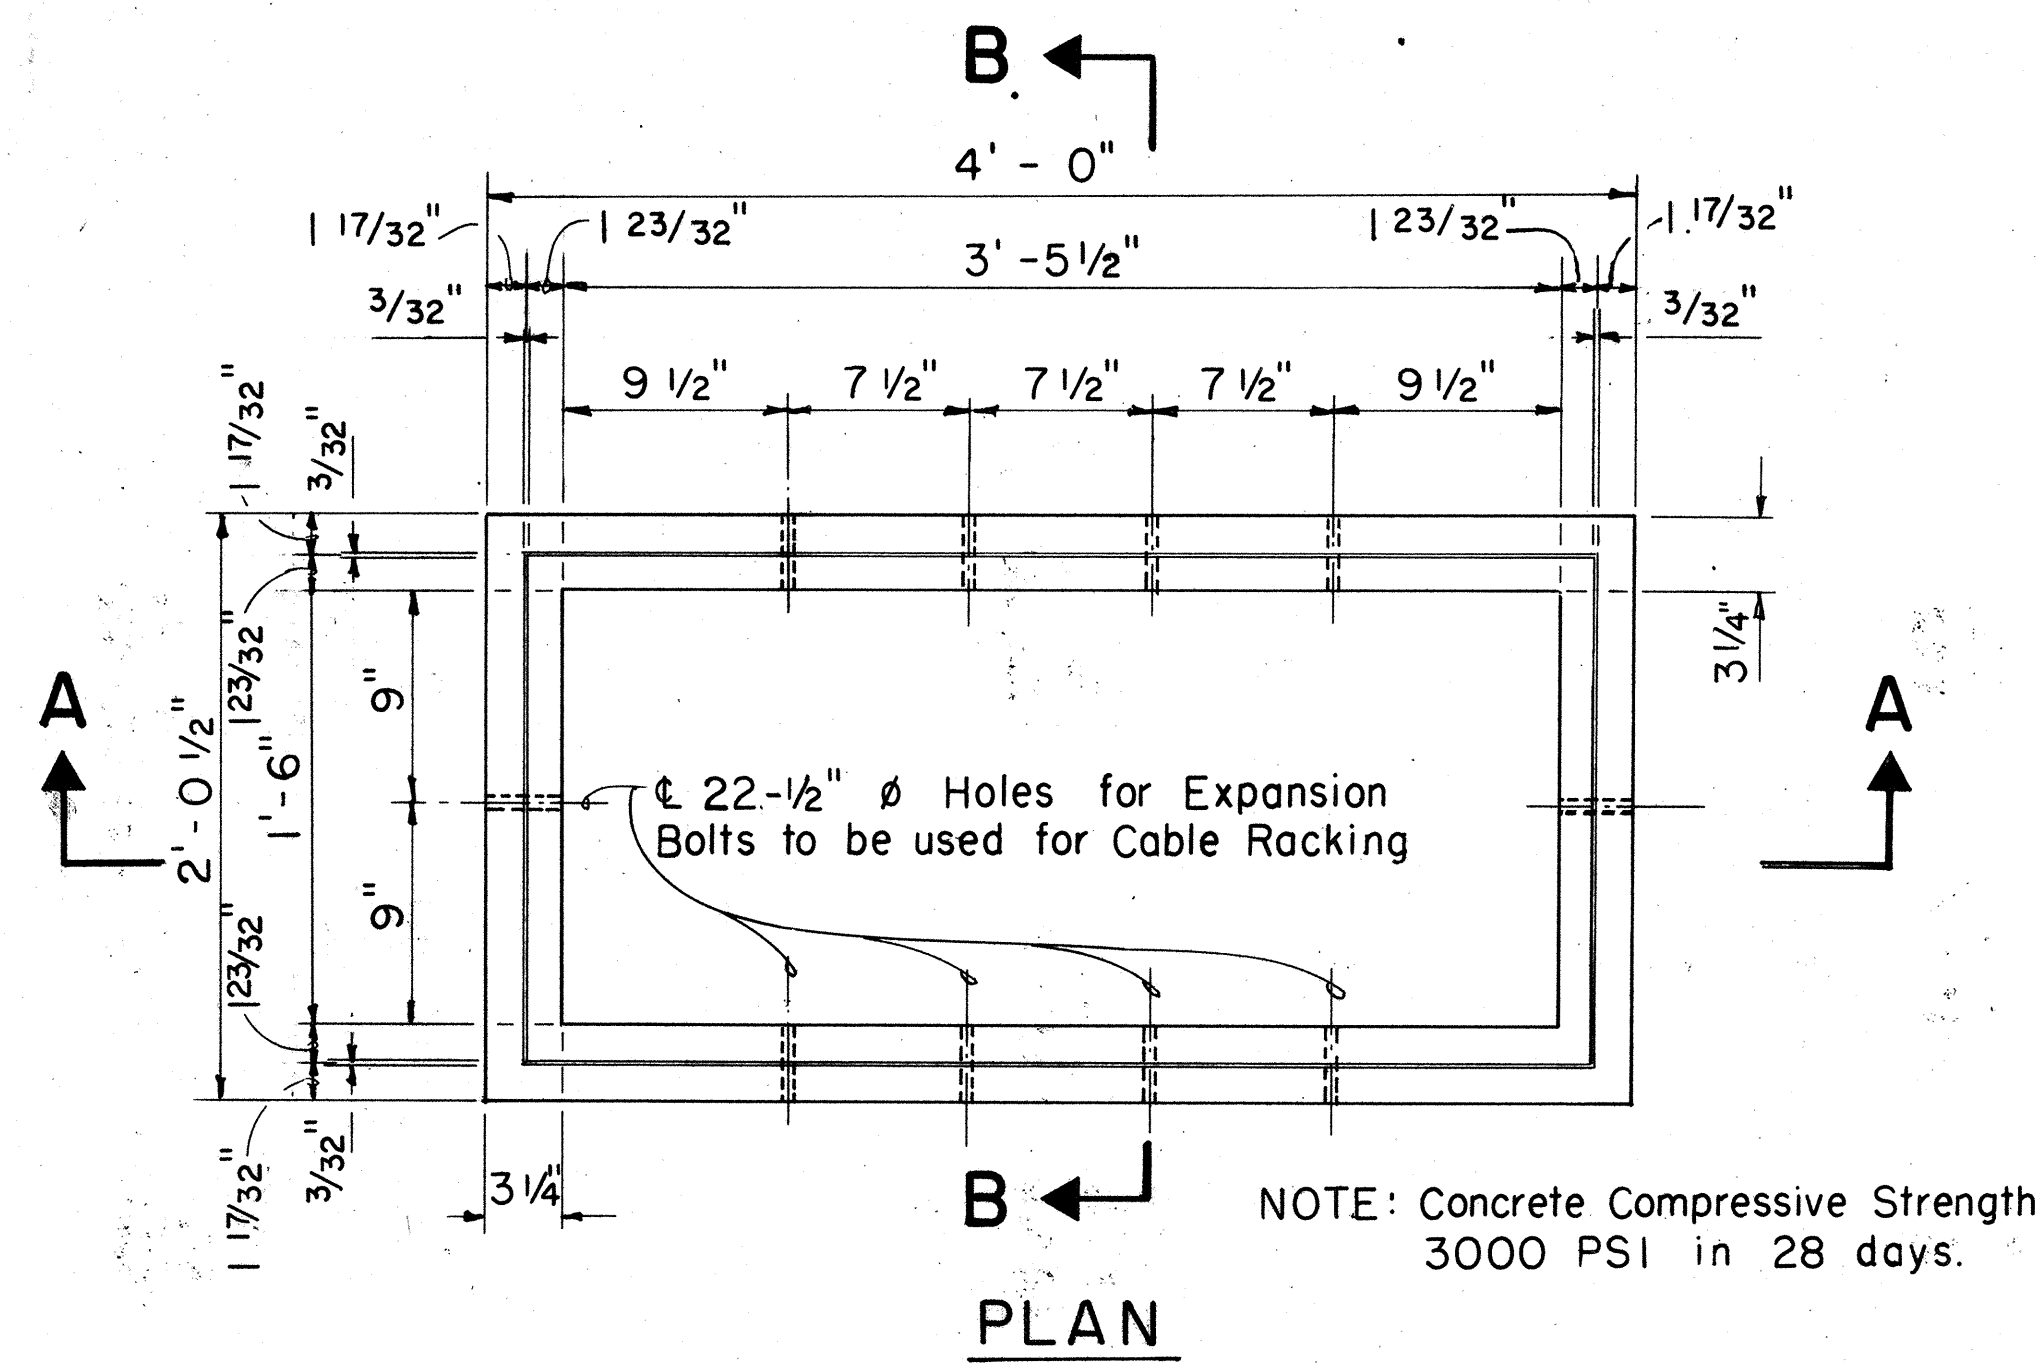

CHECKERED STEEL PLATE COVERS


FOR LIGHT LOADING AREAS-APPROX. WT. 55 LBS.

SCALE: 1 1/2" = 1'-0" (EXCEPT AS NOTED)

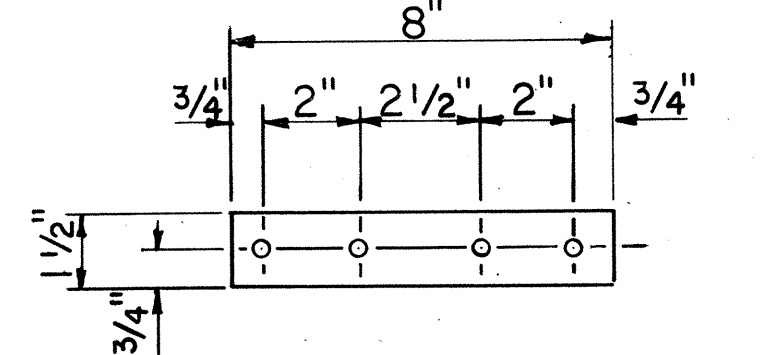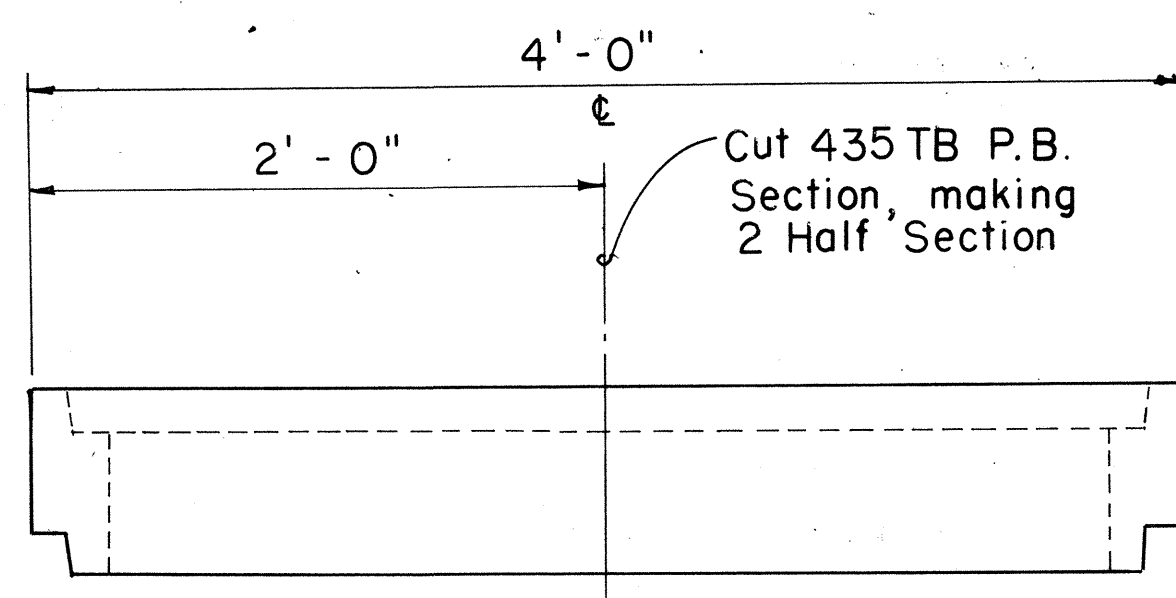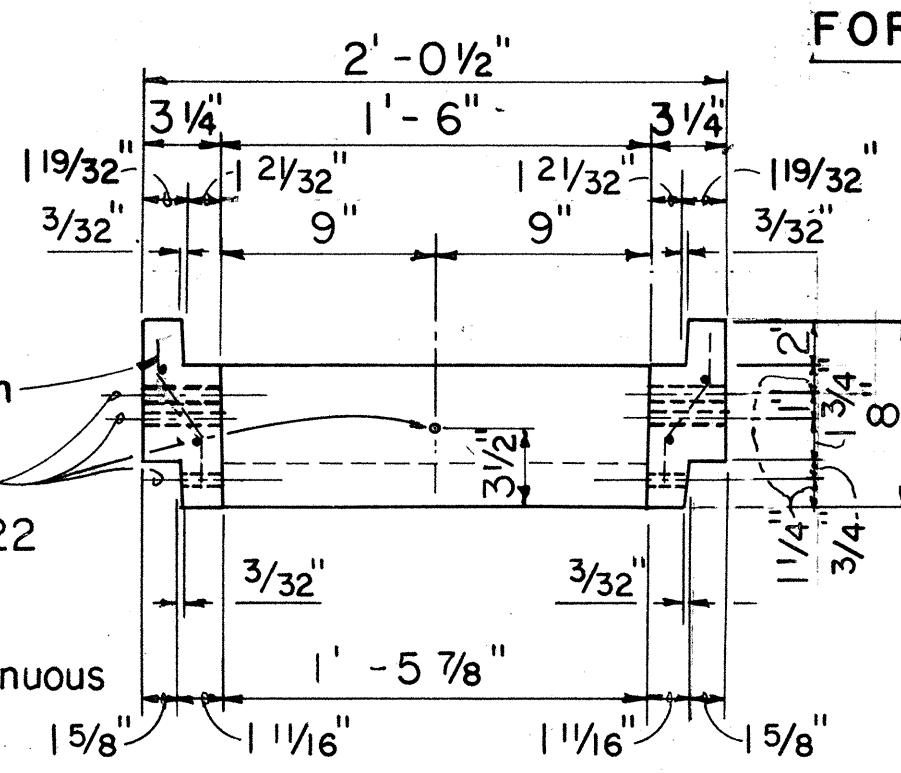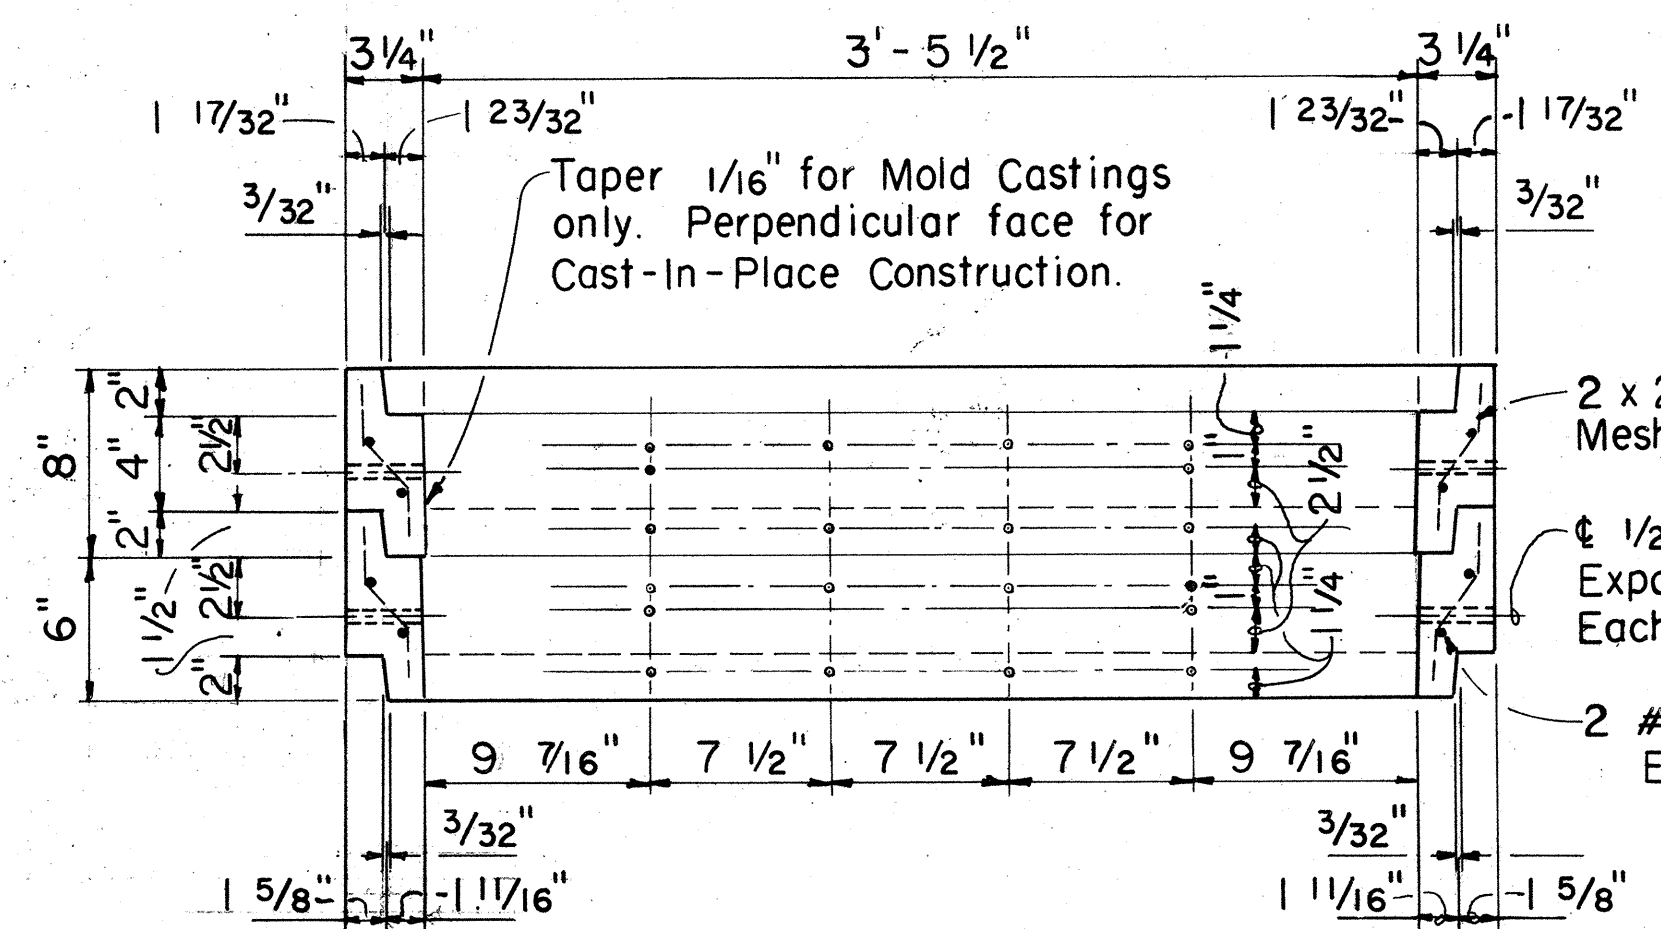


PULLBOX # 435 T-B

SCALE: 1 1/2" = 1'-0"

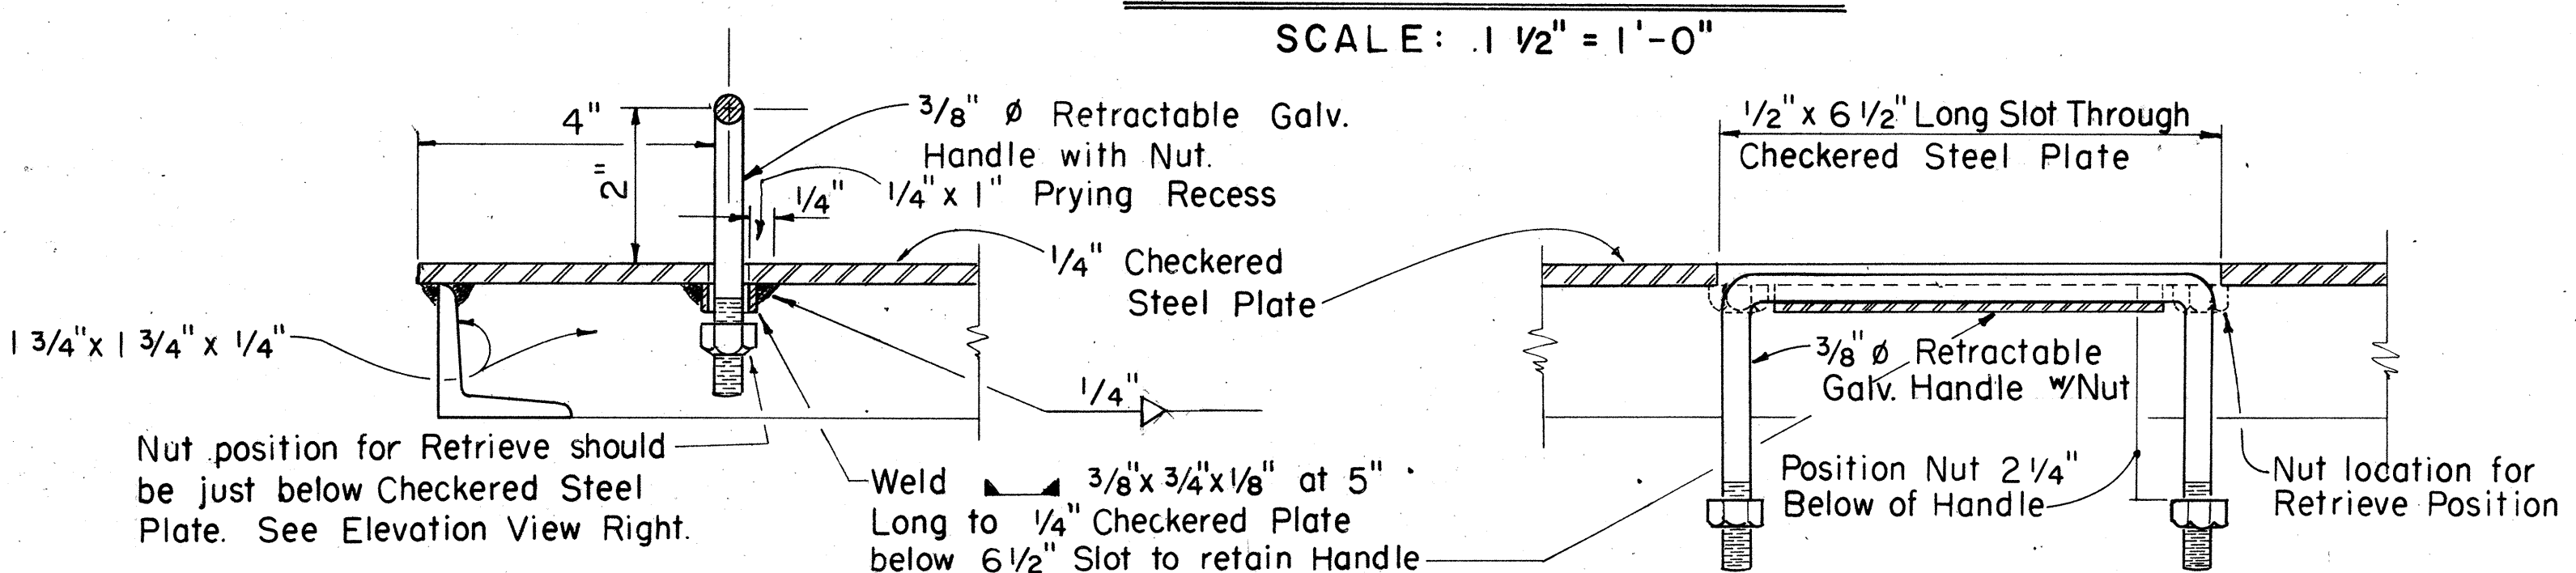

RETRACTABLE HANDLE

SCALE: 6" = 1'-0"

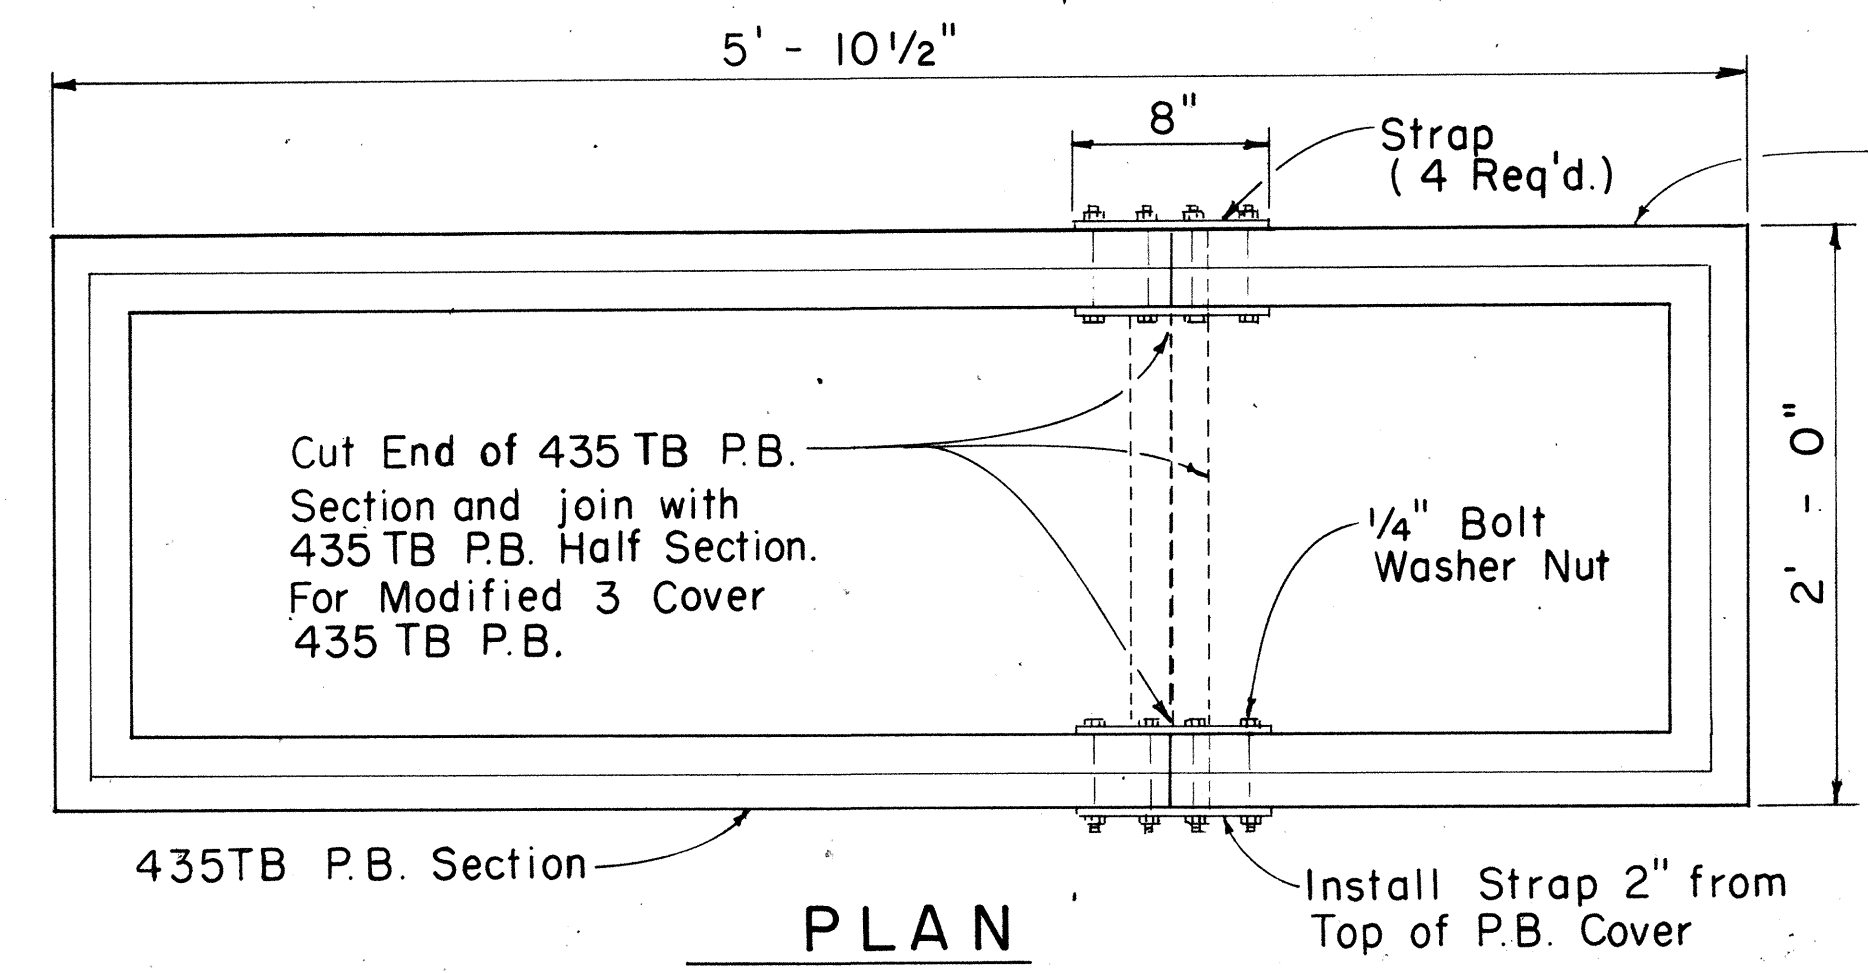

APPROVED: *[Signature]* 2-12-80 Date

Hawaiian Telephone Co., Ltd.

H.T. Co., Ltd. Drawing No. 34056


STATE OF HAWAII
DEPARTMENT OF TRANSPORTATION
LAND TRANSPORTATION FACILITIES DIVISION

LARGE PULLBOX
NO. 435 T-B


SHEET No. 2 OF 8 SHEETS

DATE	_____
SURVEY PLOTTED BY	_____
DRAWN BY	_____
DESIGNED BY	_____
NOTED BY	_____
CHECKED BY	_____
ORIGINAL PLAN	_____
NOTE BOOK	_____
No.	_____


FED. ROAD DIST. NO.	STATE	FED. AID PROJ. NO.	FISCAL YEAR	SHEET NO.	TOTAL SHEETS
HAWAII	HAW.	M-760012	1980	145	244

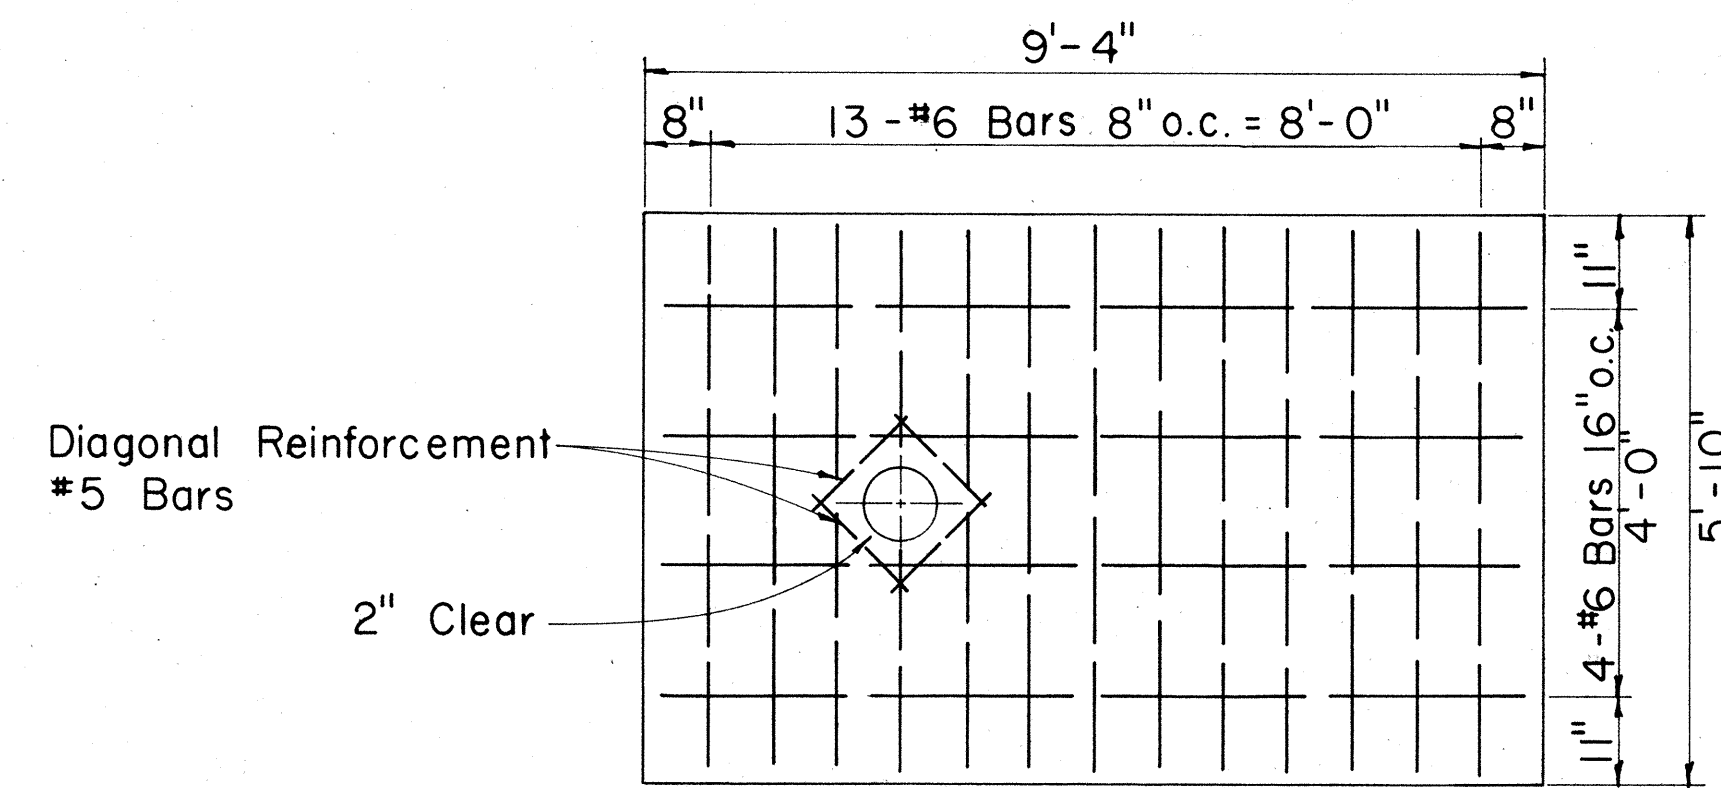

FLOOR SLAB REINF. PLAN
Scale: 1/2" = 1'-0"

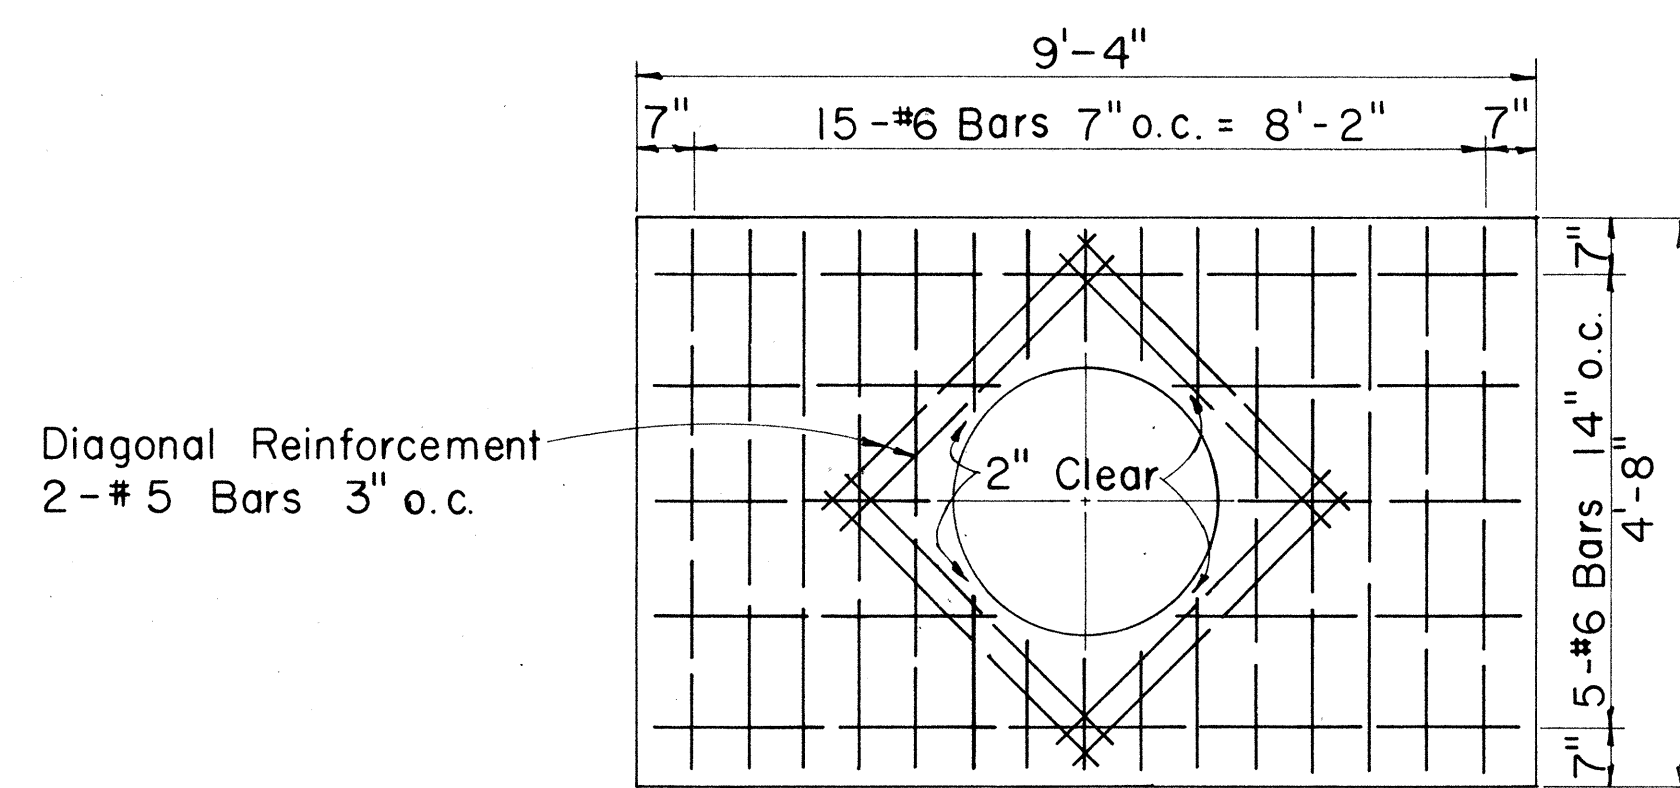


ROOF SLAB REINF. PLAN
Scale: 1/2" = 1'-0"

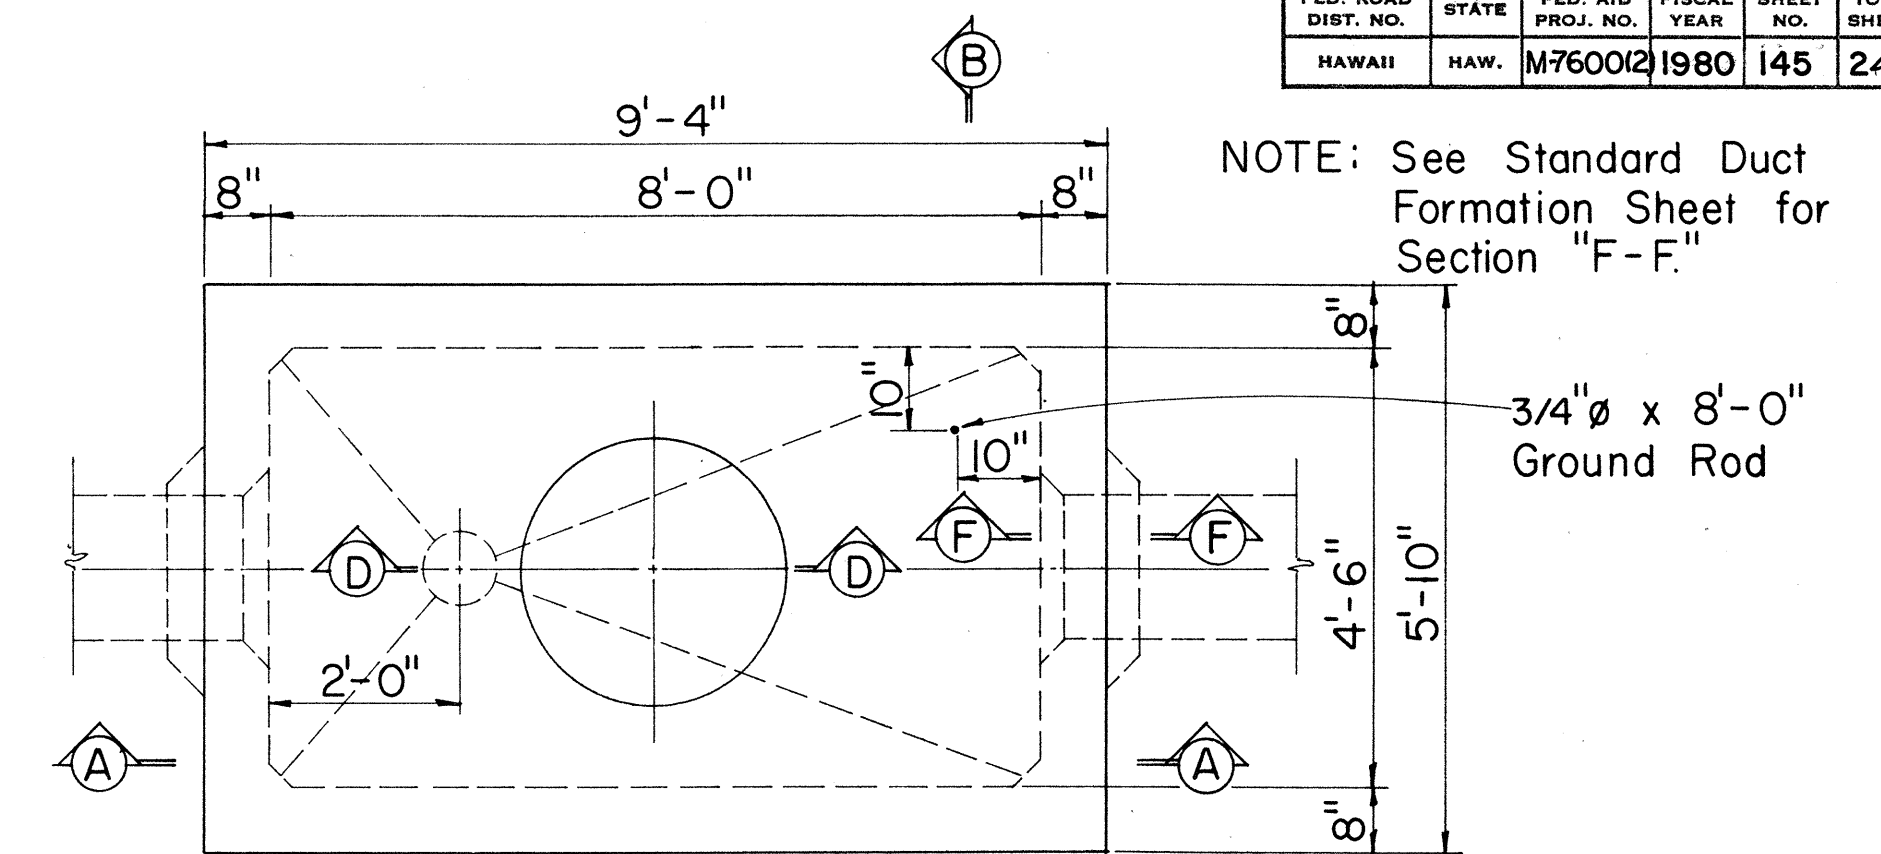

PLAN M.H. TYPE "A-1"
FOR ROADWAY & SIDEWALK AREAS
Scale: 1/2" = 1'-0"

NOTE: See Standard Duct Formation Sheet for Section "F-F."


3/4" ϕ x 8'-0" Ground Rod

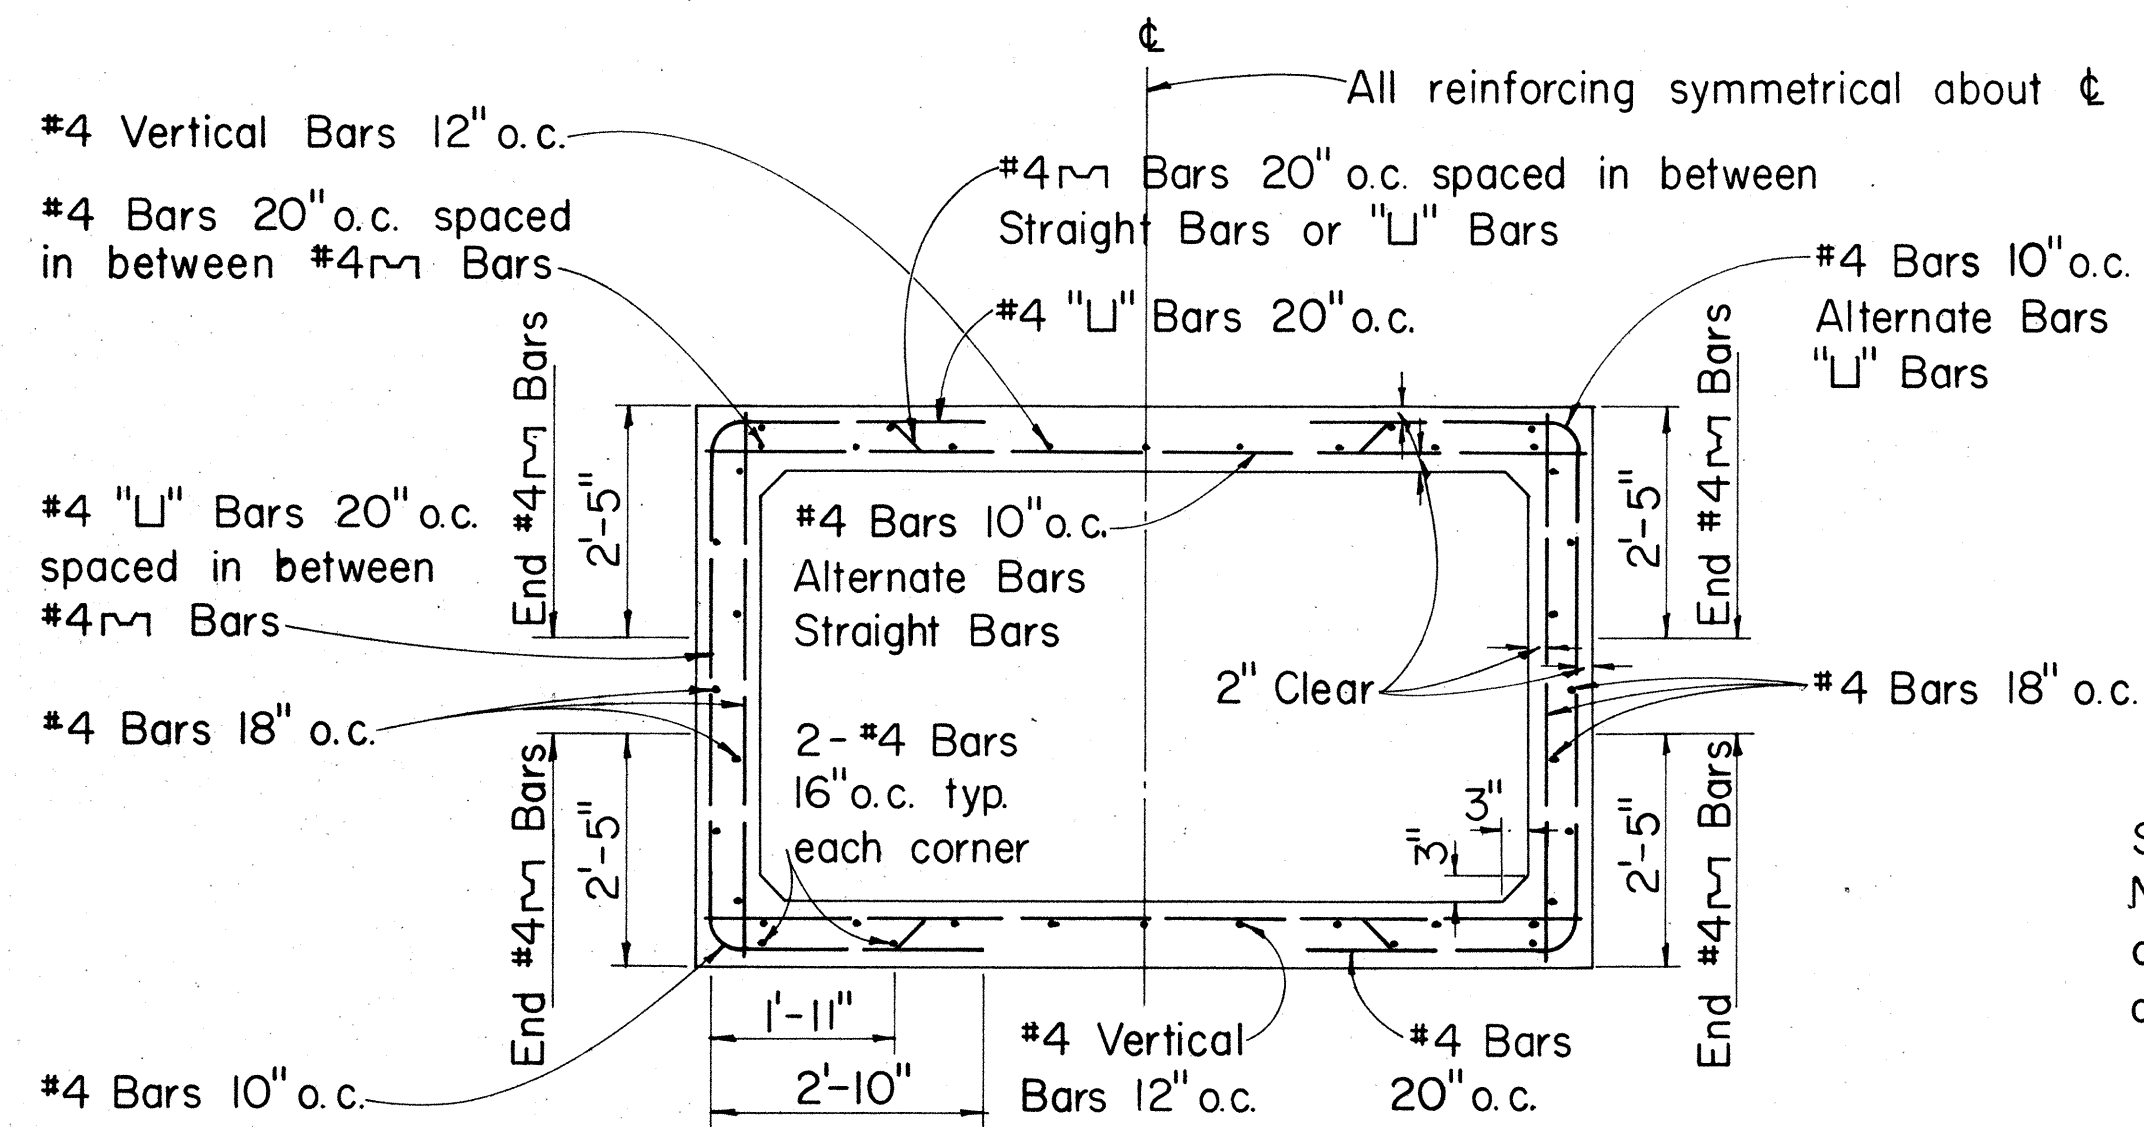


SECTION "C-C"
Scale: 1/2" = 1'-0"

For Diagonal Reinforcement place 2-#5 Bars 3" o.c. typical around all Duct Bank Entrances


For location of Pulling-In Iron see Elevation of Manhole Walls.

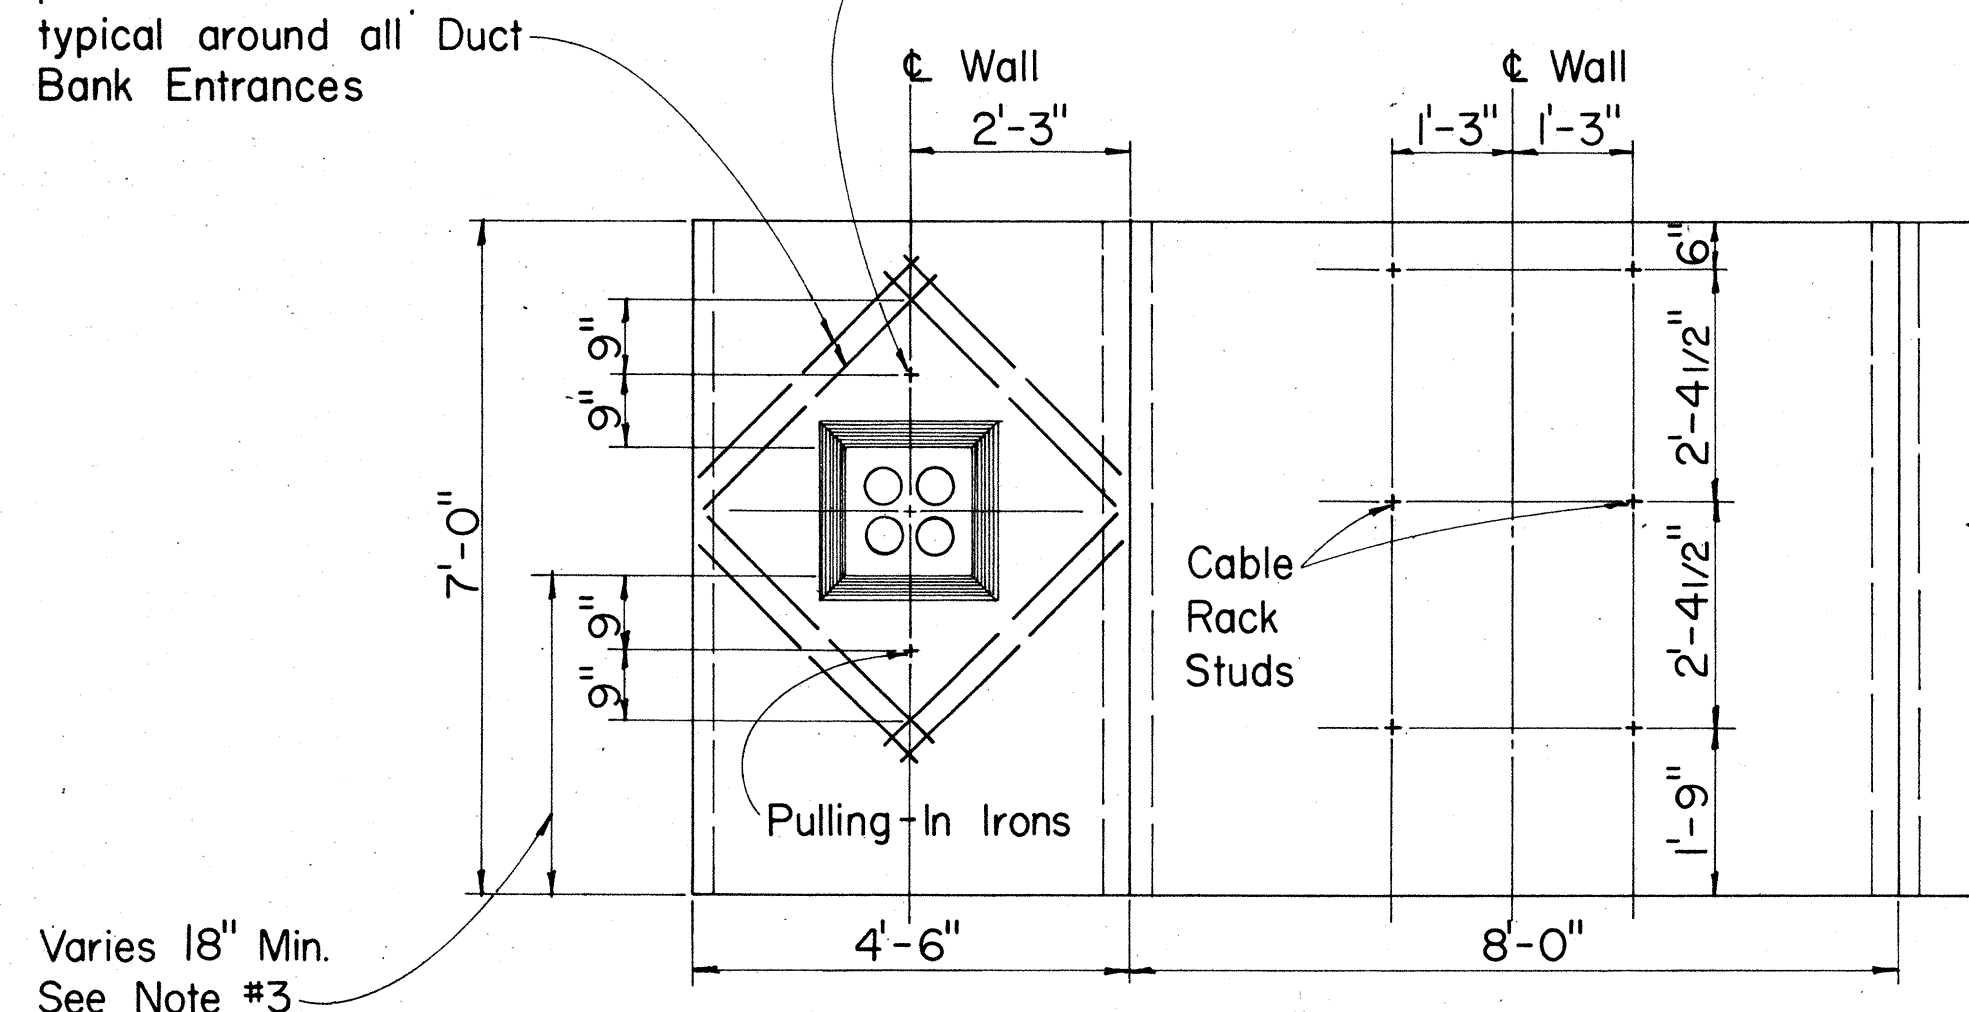

ELEVATION OF M.H. WALLS
(OPPOSITE FACES SIMILAR)
Scale: 1/2" = 1'-0"

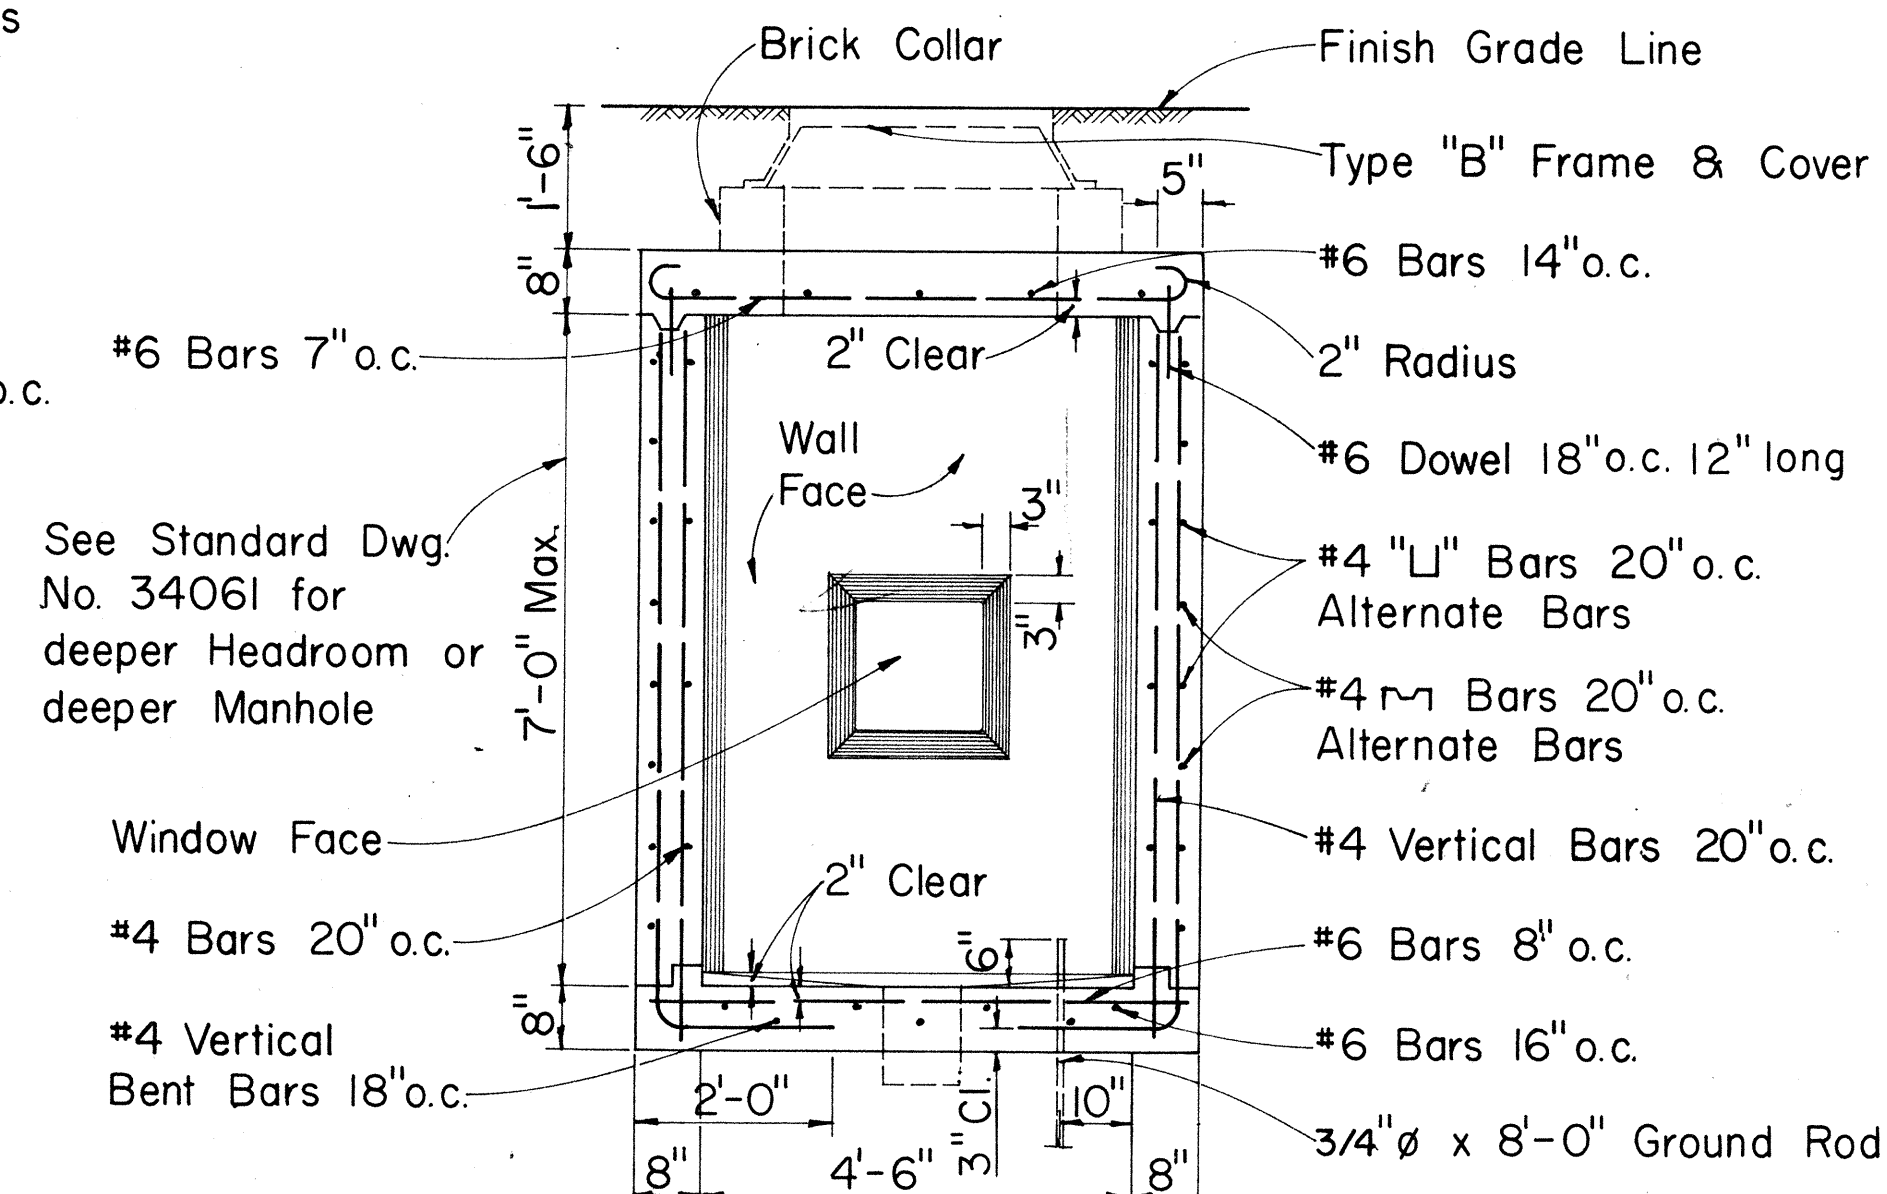


SECTION "B-B"
Scale: 1/2" = 1'-0"

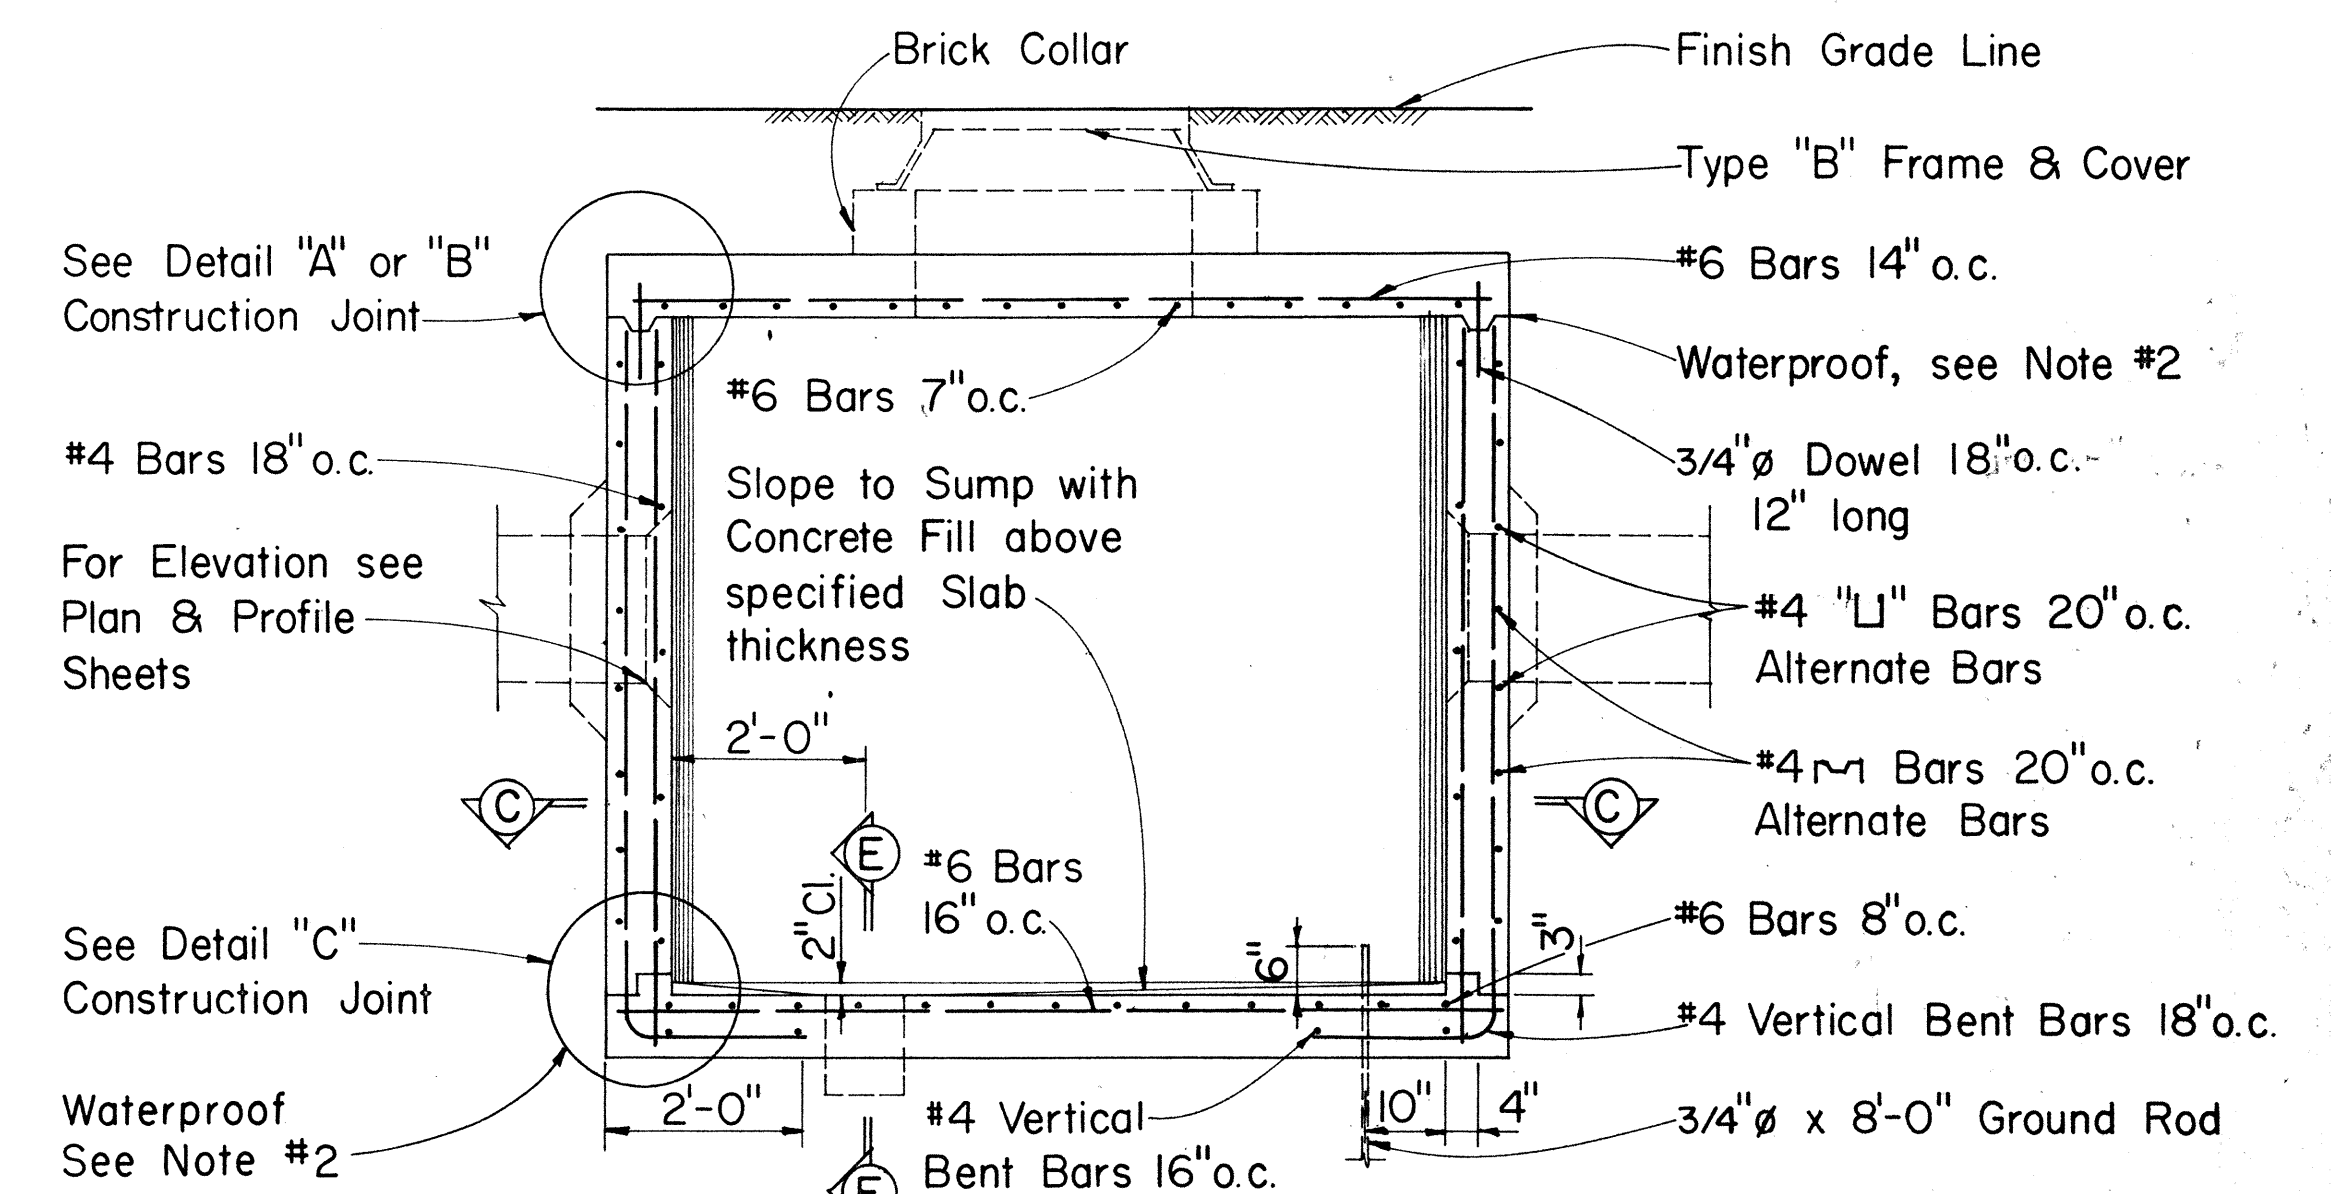

SECTION "A-A"
Scale: 1/2" = 1'-0"


GENERAL NOTES

- Design Data:
 $f_s = 20,000$ psi, $f_c = 3,000$ psi, $f_c = 1,350$ psi, $n = 10$
 $w =$ Equivalent Fluid Pressure: 30 k/ft^2
- All Construction Joints shall be waterproofed with two applications of Thoro Seal or equal.
- For Duct Window location see Plan Profile Sheets for Elevations.
- Duct Window to suit-See Plan & Profile & Standard Detail Sheets for Location & Details.
- For Details "A", "B", "C", Sections "D-D", "E-E", "F-F", and other miscellaneous Manhole Construction Details see Supplement Sheet to Type A-1, A-2, and A-3 Telephone Manholes.

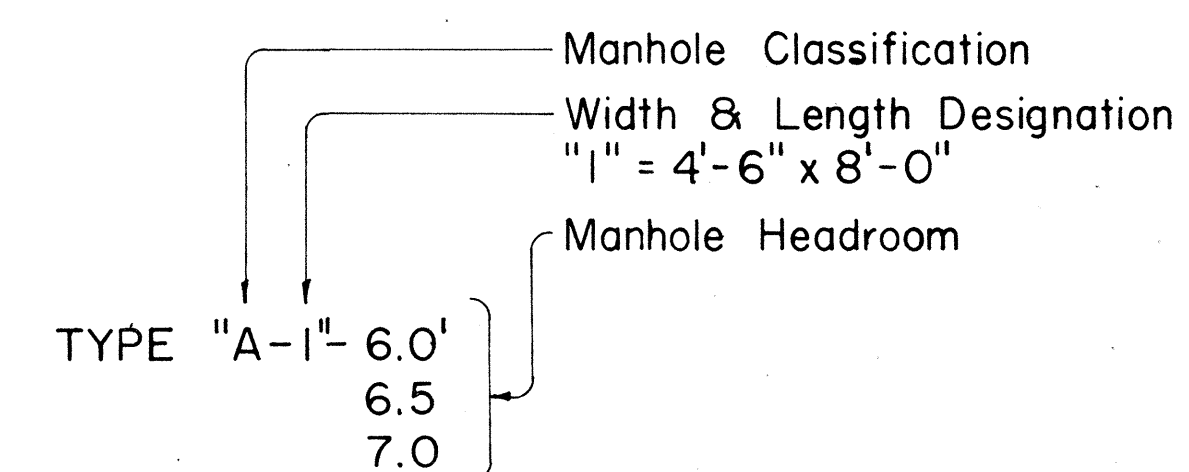


APPROVED:	
<i>G. Yamada</i>	2-12-80
Hawaiian Telephone Co., Ltd.	Date
H. T. Co., Ltd.	Drawing No. 34060
STATE OF HAWAII DEPARTMENT OF TRANSPORTATION LAND TRANSPORTATION FACILITIES DIVISION	
TYPE "A-1" MANHOLES FOR 6.0' TO 7.0' HEADROOM	
Scale: As Noted	Date: SEPT 1979
SHEET No. 3 OF 8 SHEETS	


FED. ROAD DIST. NO.	STATE	FED. AID PROJ. NO.	FISCAL YEAR	SHEET NO.	TOTAL SHEETS
HAWAII	HAW.	M-7600 (2)	1980	146	244

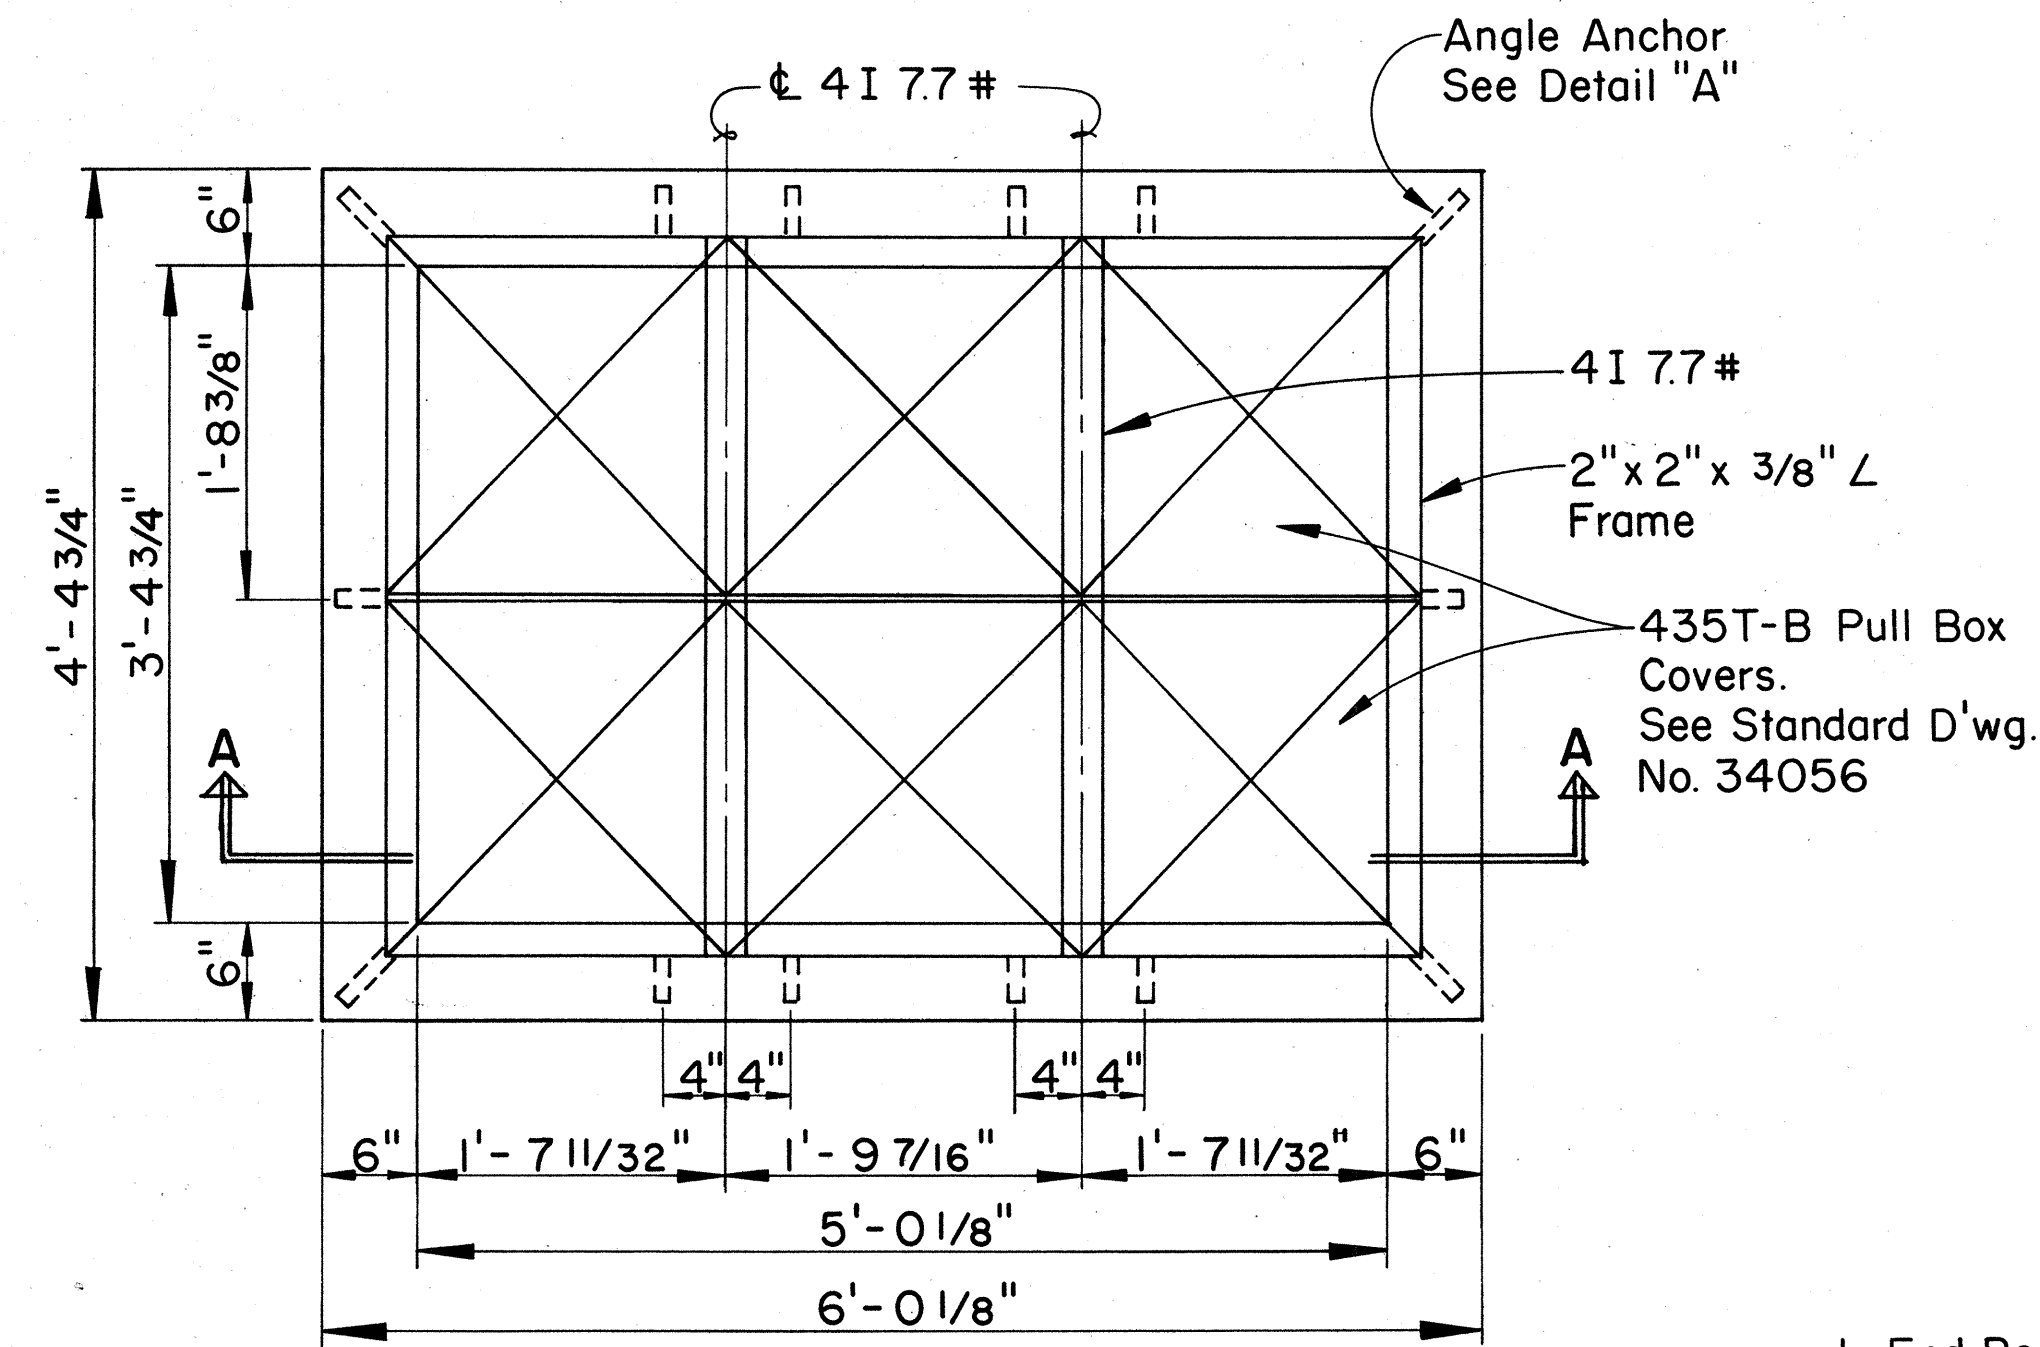


TOP PLAN
Scale: 1" = 1'-0"

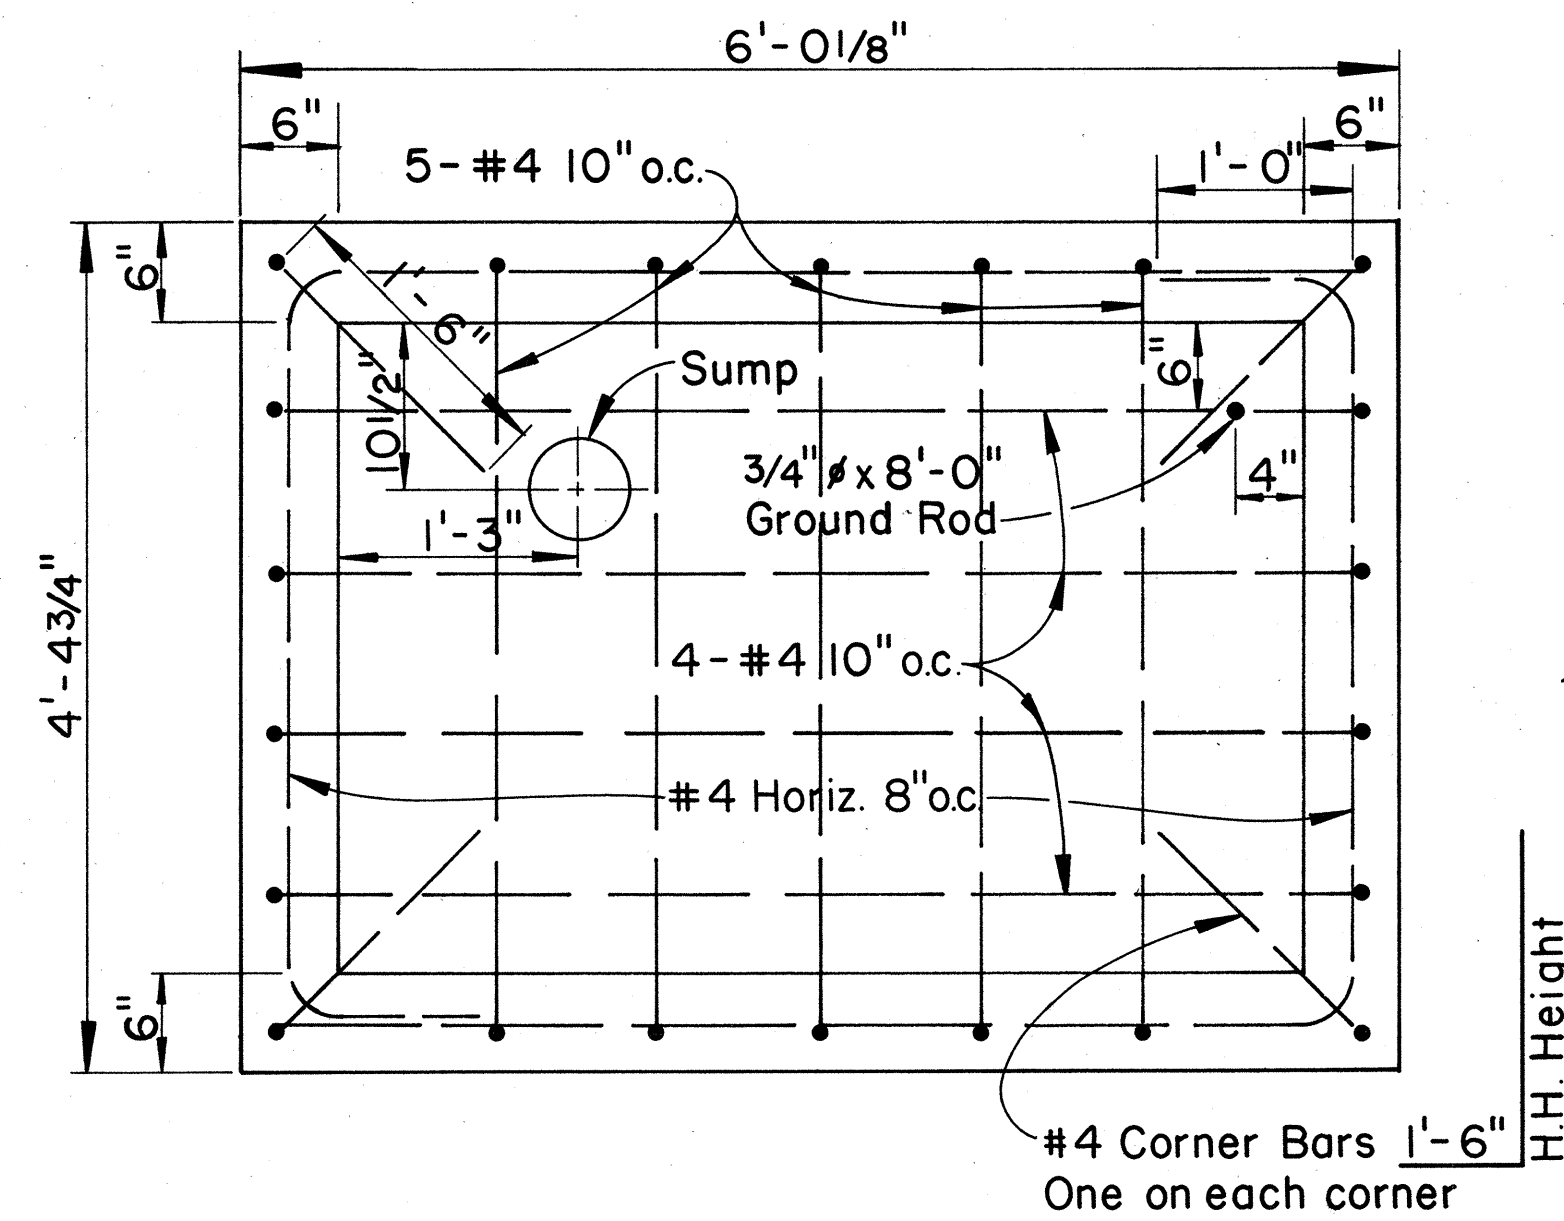


FLOOR PLAN
Scale: 1" = 1'-0"

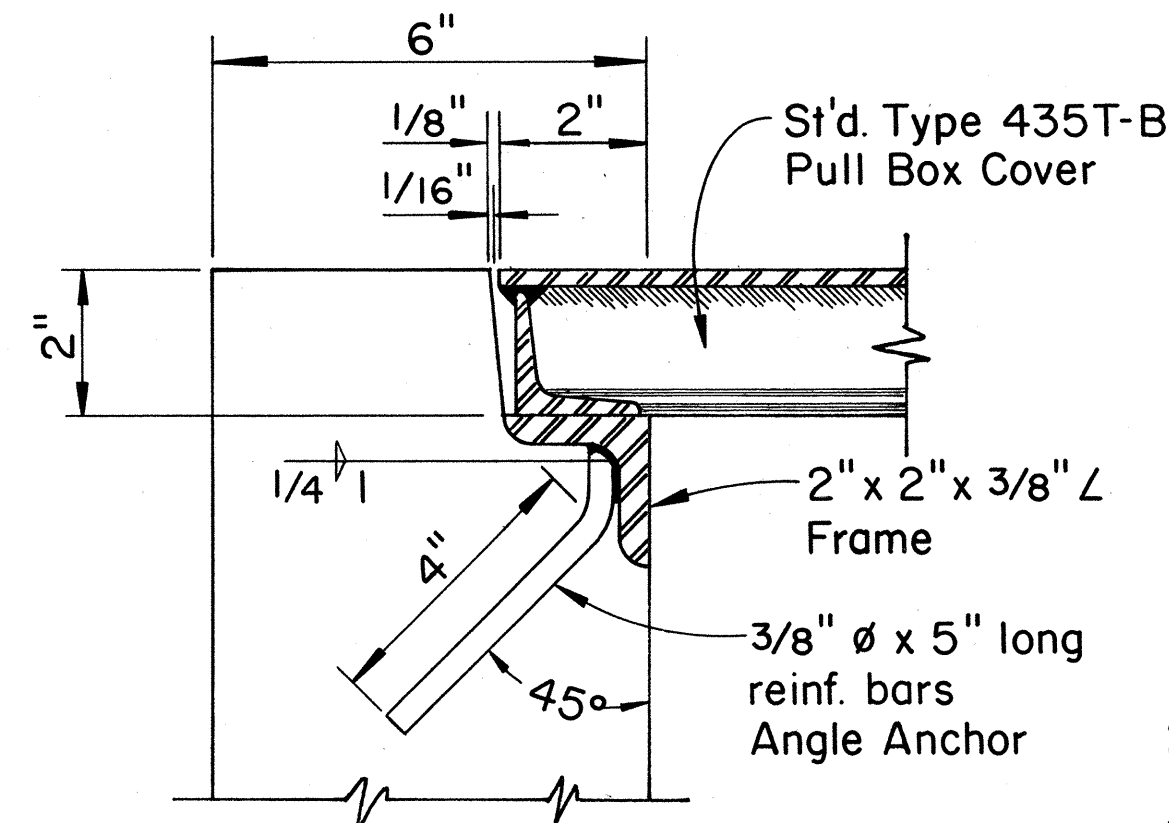


NOTE:
Section is typical.
DETAIL "A"
Scale: 3/8" = 1"

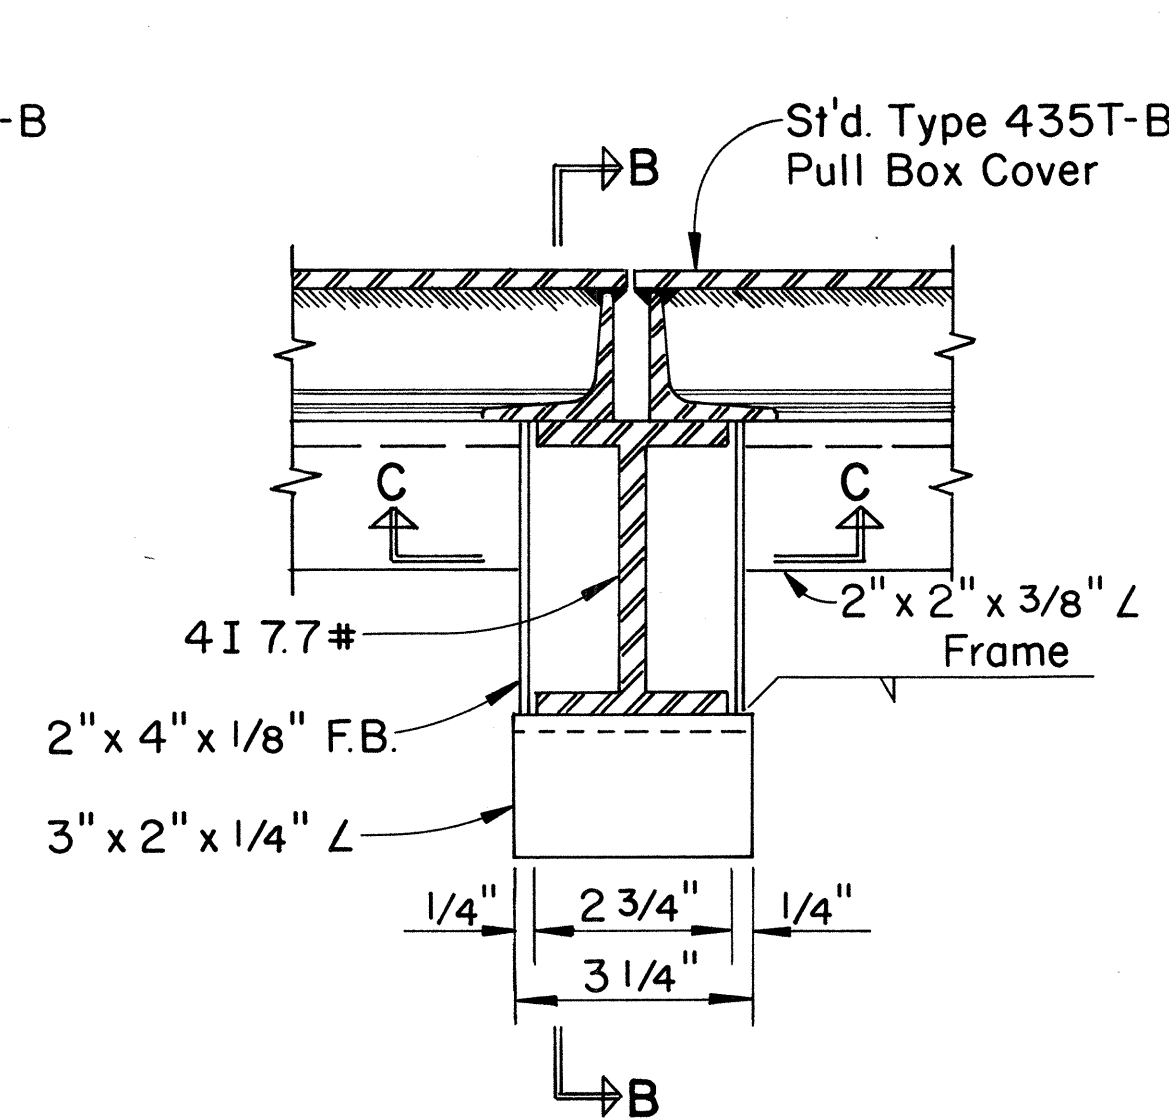

DETAIL "B"
Scale: 3/8" = 1"

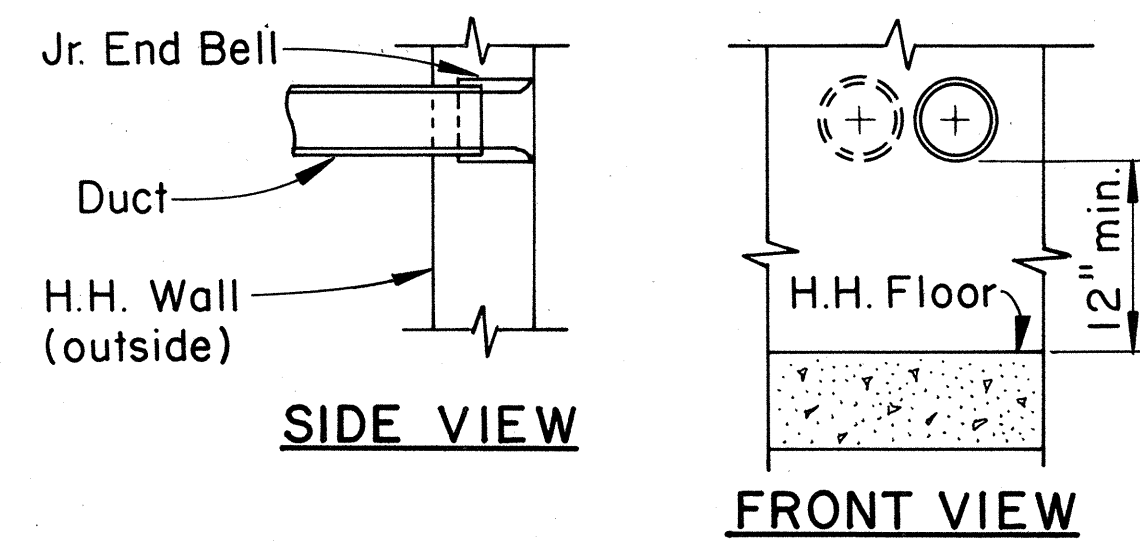

1 OR 2 DUCTS
Scale: 1" = 1'-0"

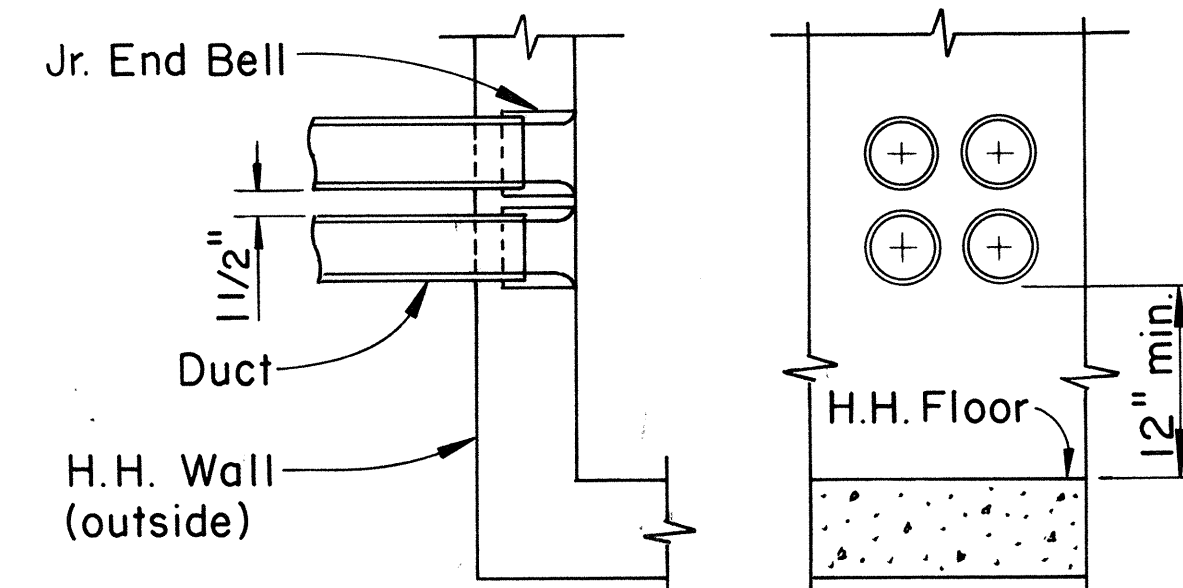


4 DUCTS
DUCT ENTRANCE DETAILS
Scale: 1" = 1'-0"


Diag. Reinf. 2-#5 at 3" o.c. over Duct Entrance.

No. of Ducts & Location shall be determined by the project.


See Duct Entrance Details this sheet.

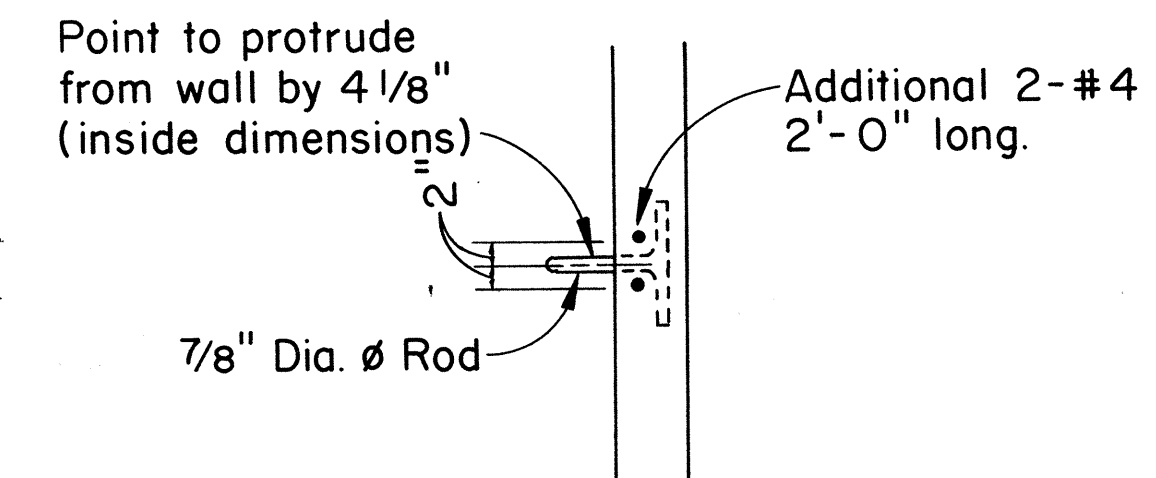


SECTIONAL ELEV. OF PULL-IN IRON
Scale: 3/4" = 1'-0"

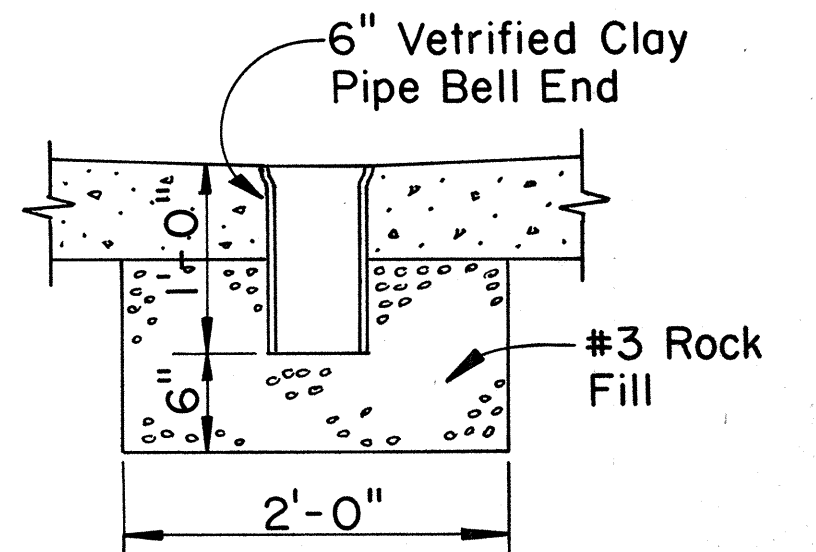

DETAIL OF SUMP
Scale: 1" = 1'-0"

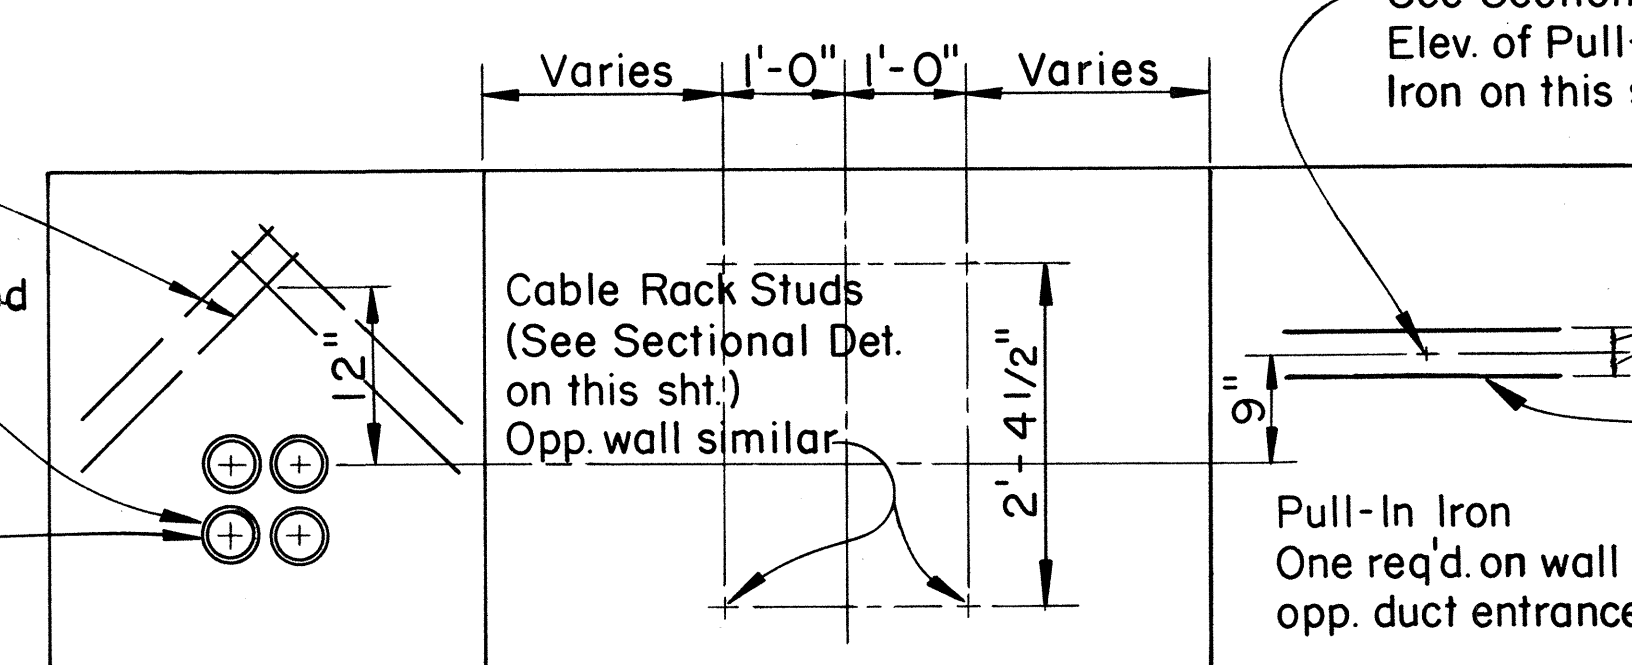

ELEV. OF INSIDE WALLS - H.H. TYPE I
Scale: 3/4" = 1'-0"

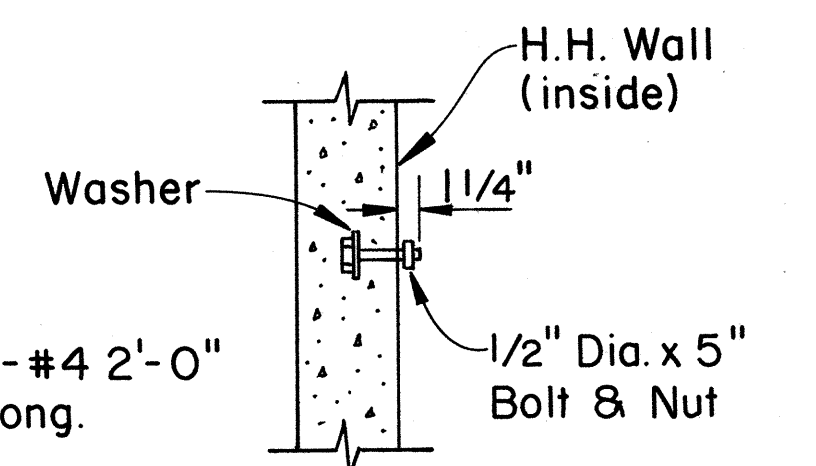

CABLE RACK STUD

BOLT DETAIL
Scale: 1" = 1'-0"

GENERAL NOTES:

- Concrete finish: floors-wood floated finish-exposed wall surfaces and edges-smooth and free from defects.
- Concrete to develop compressive strength-3000 p.s.i. in 28 days.
- Steel work all structural steel shall be hot dip galvanized after fabrication.
- For duct line construction standards, see st'd. dwg. No. 34028.
- These handholes are designed for installation in areas other than roadways.

APPROVED:

HAWAIIAN TELEPHONE CO., LTD.








DATE

STATE OF HAWAII
DEPARTMENT OF TRANSPORTATION
LAND TRANSPORTATION FACILITIES DIVISION



**STANDARD HANDHOLE,
TYPE #1 USING TYPE
435T-B PULLBOX COVERS**

Scale: As Shown Date: SEPT 1979
SHEET No. 4 OF 8 SHEETS


FED. ROAD DIST. NO.	STATE	FED. AID PROJ. NO.	FISCAL YEAR	SHEET NO.	TOTAL SHEETS
HAWAII	HAW.	M-7600 (2)	1980	147	244

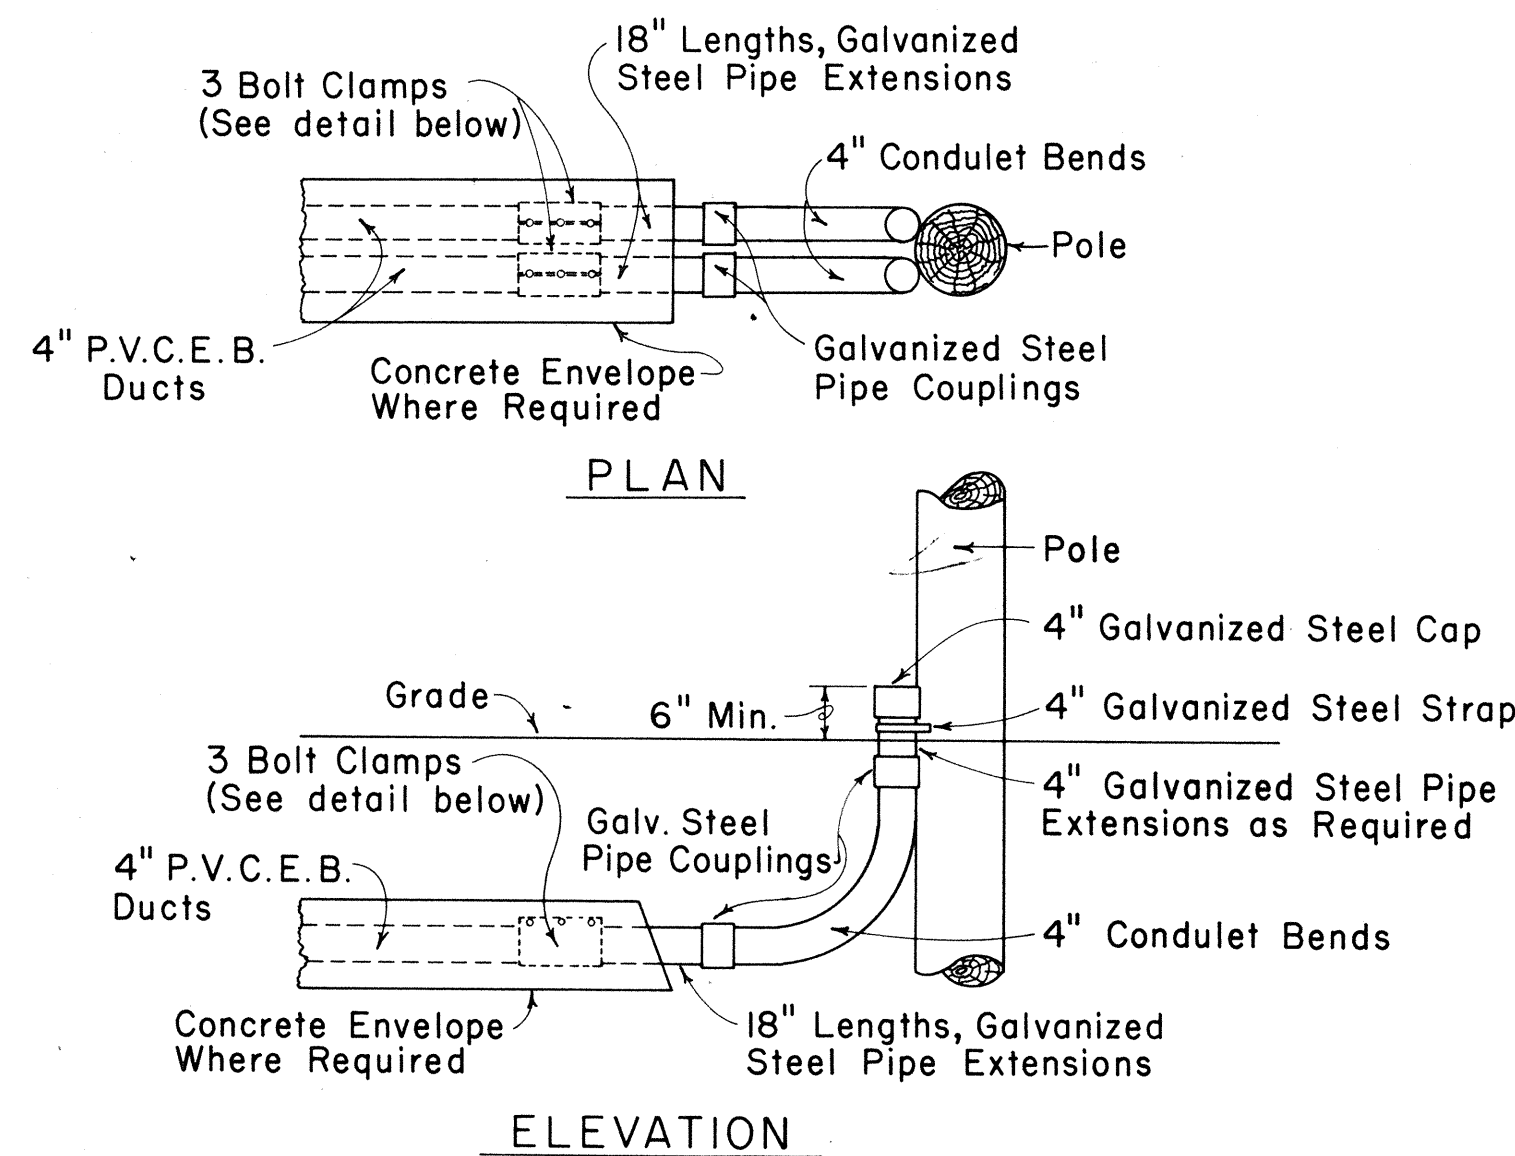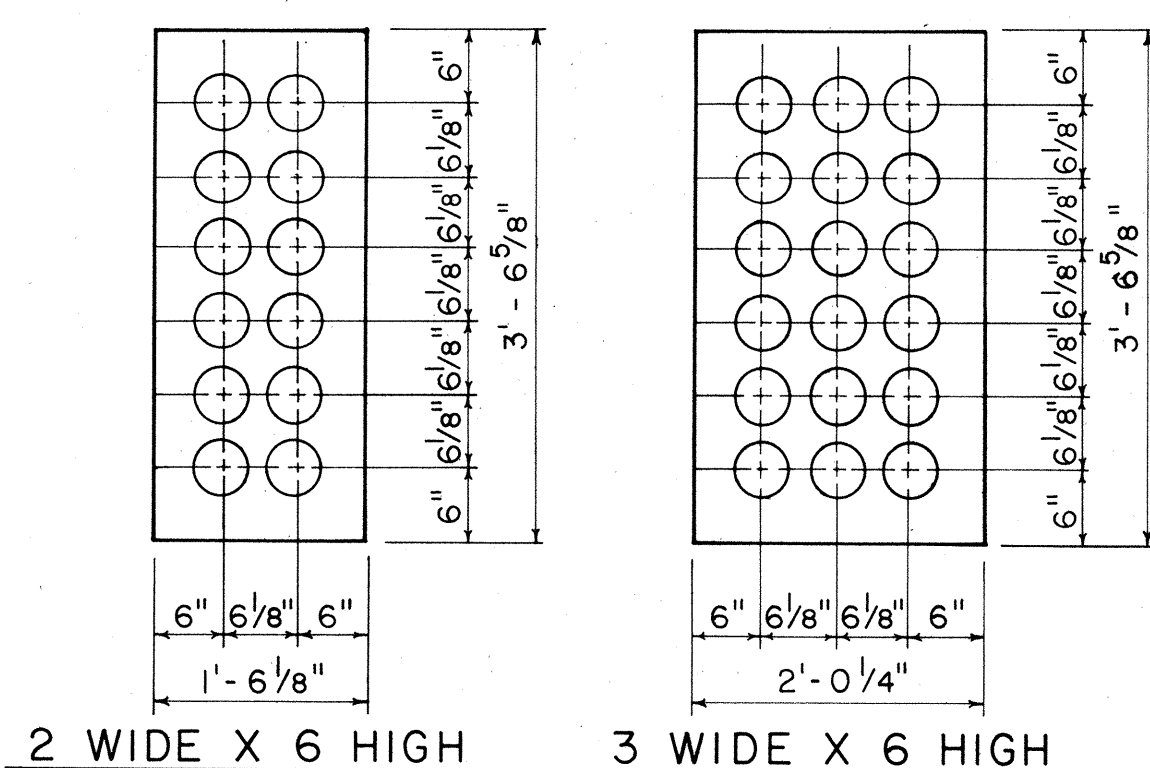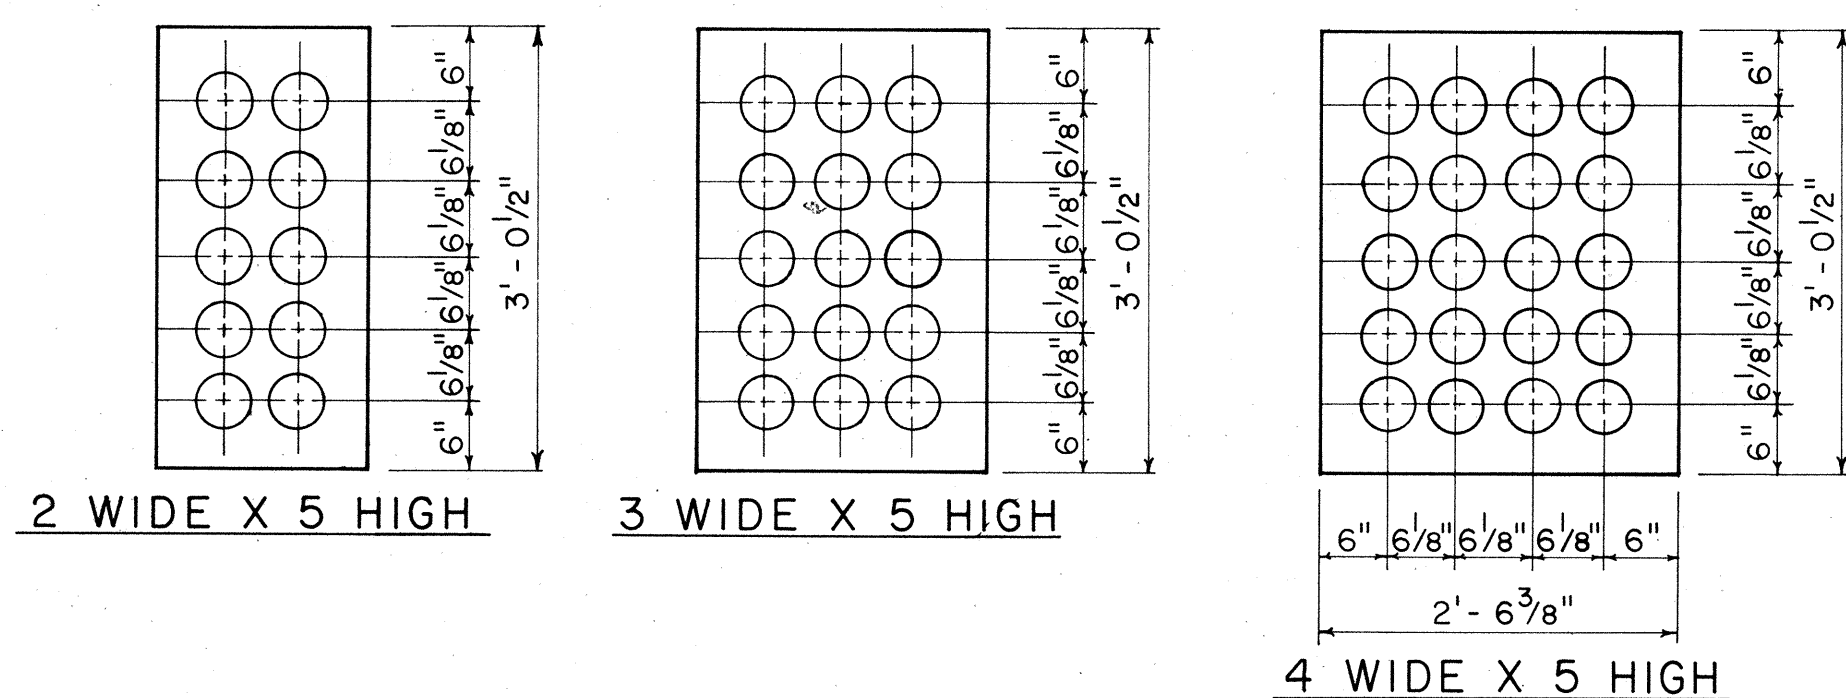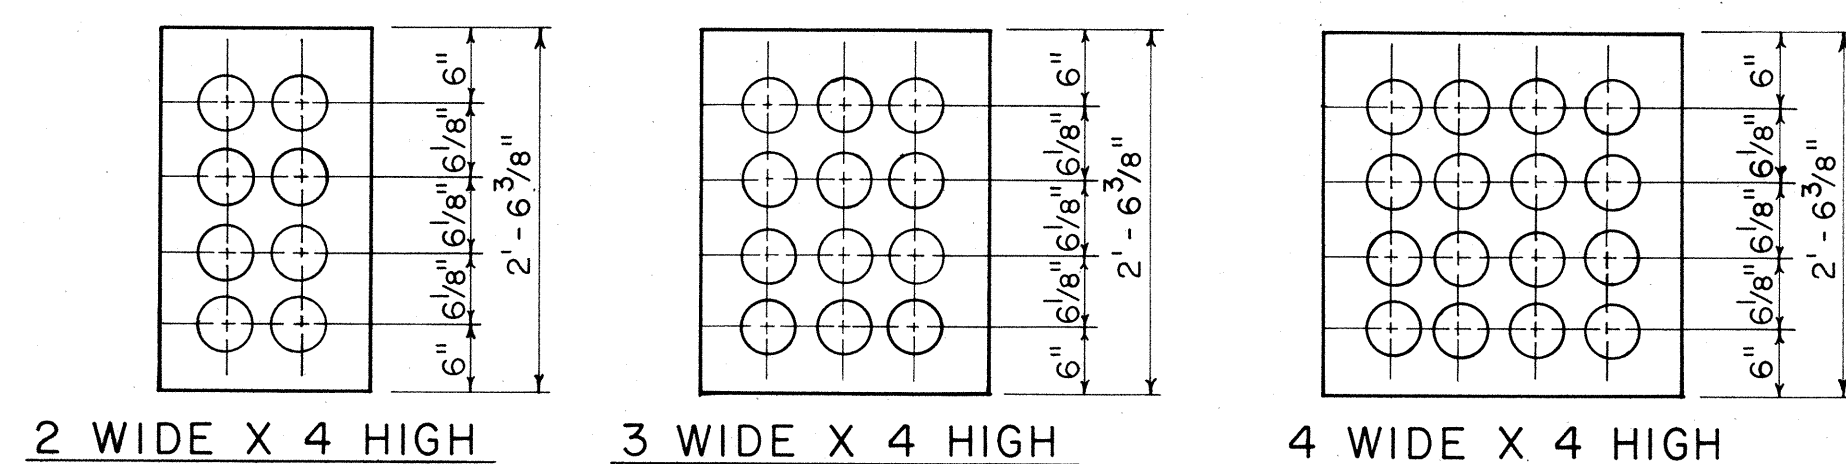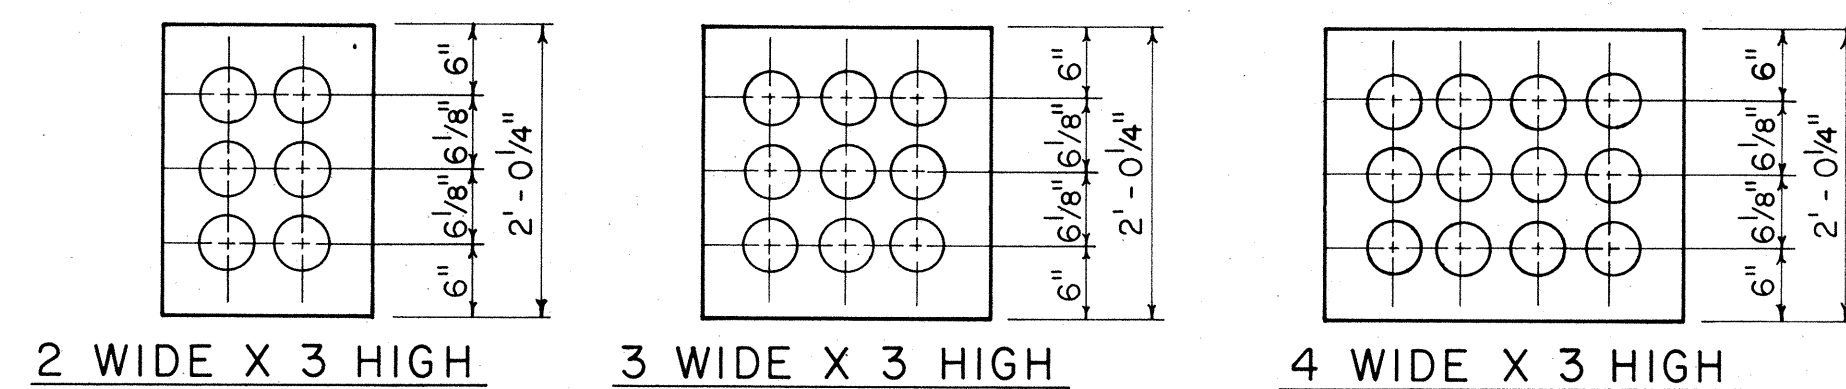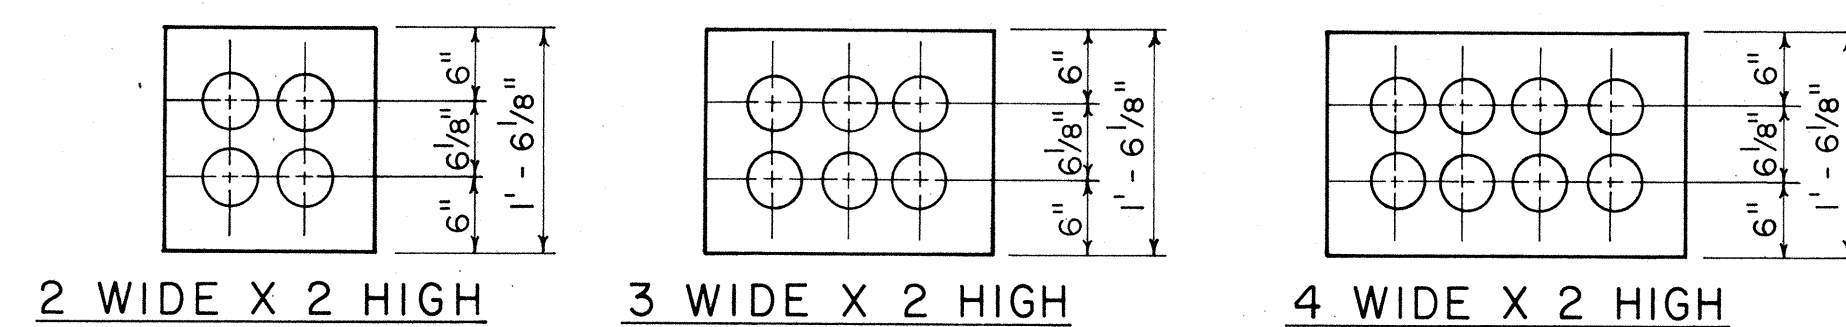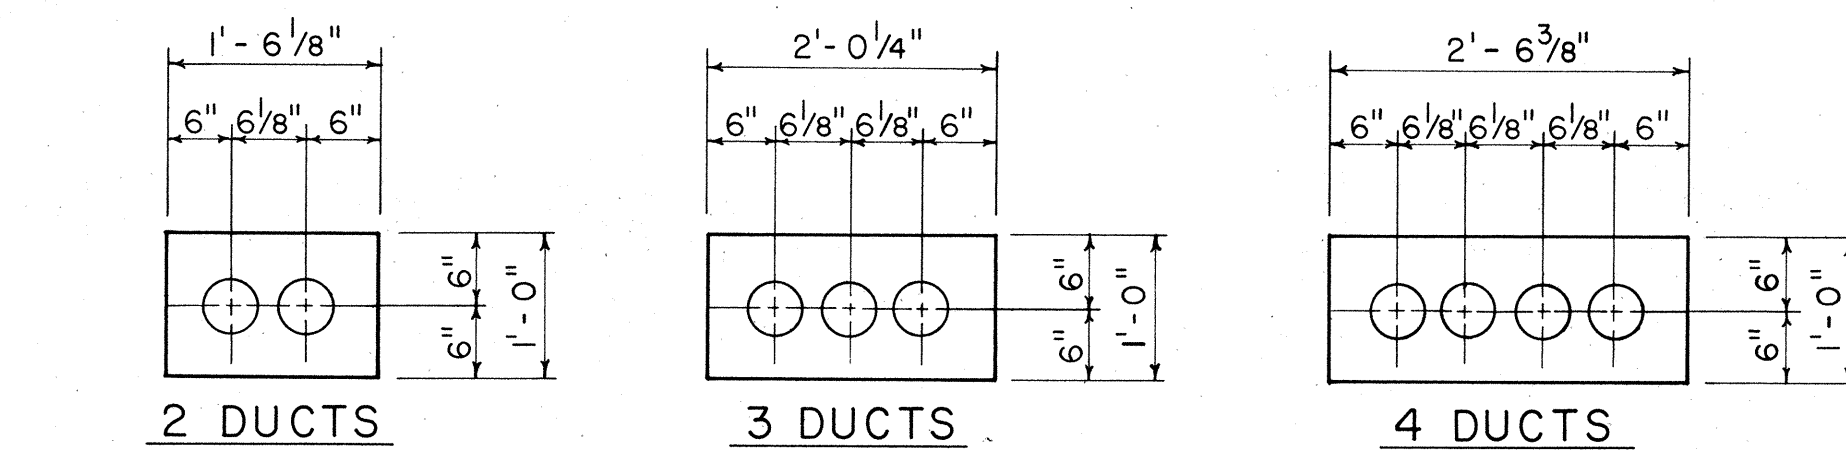


TYPICAL INSTALLATION DETAILS

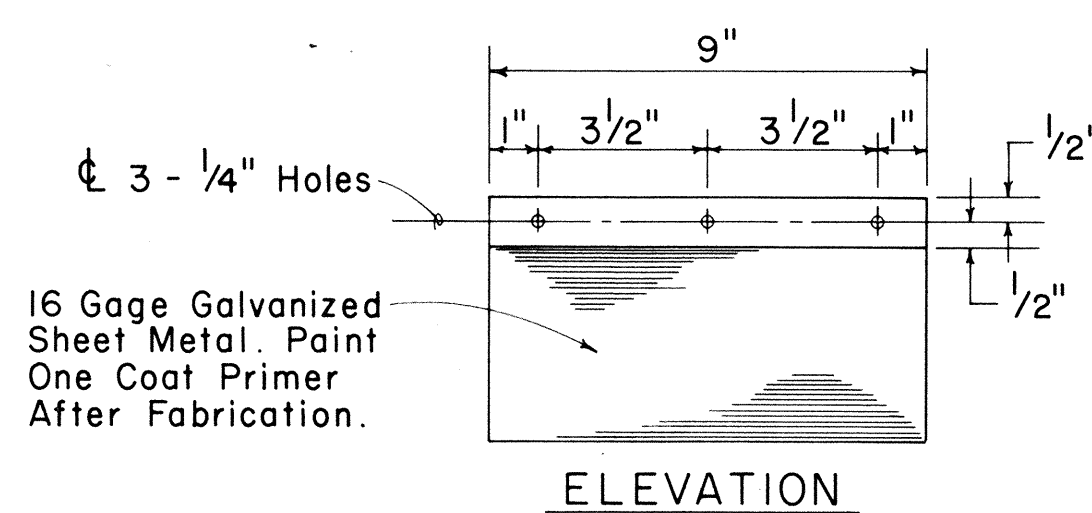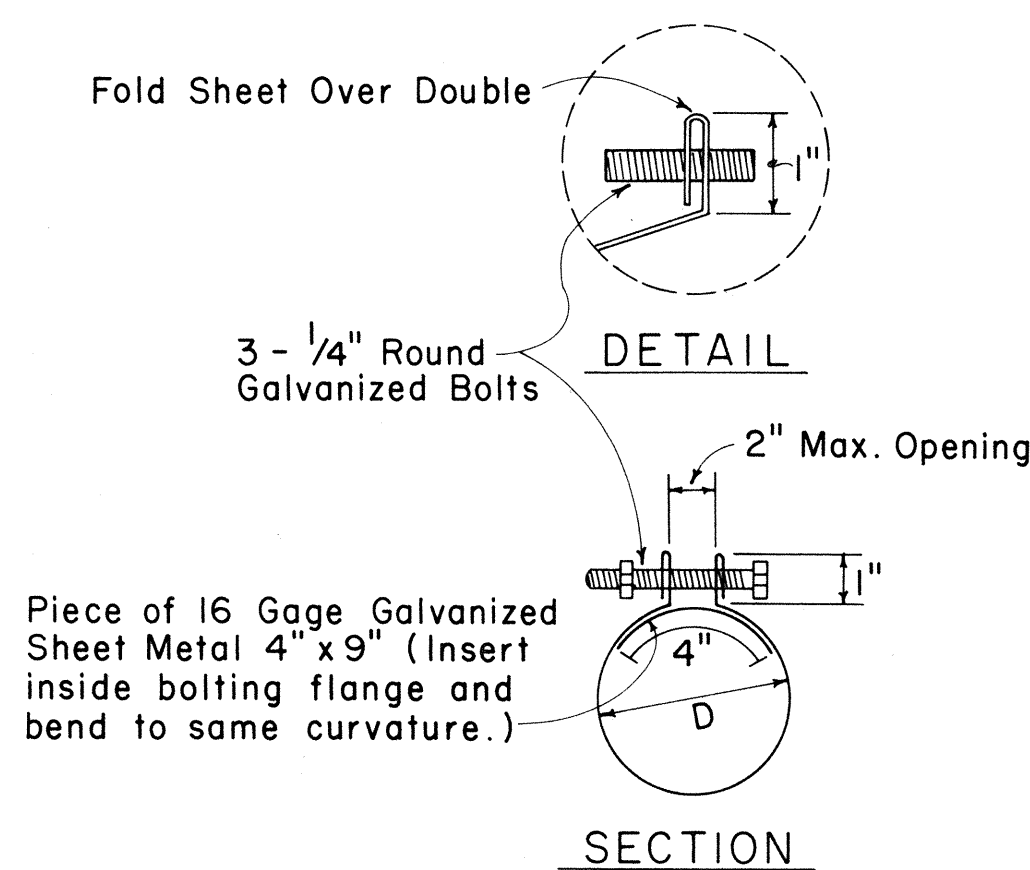

3-BOLT CLAMP ADAPTOR DETAIL

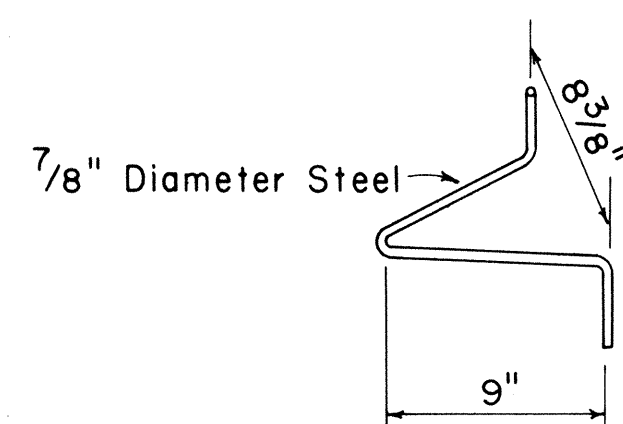


PULLING-IN IRON

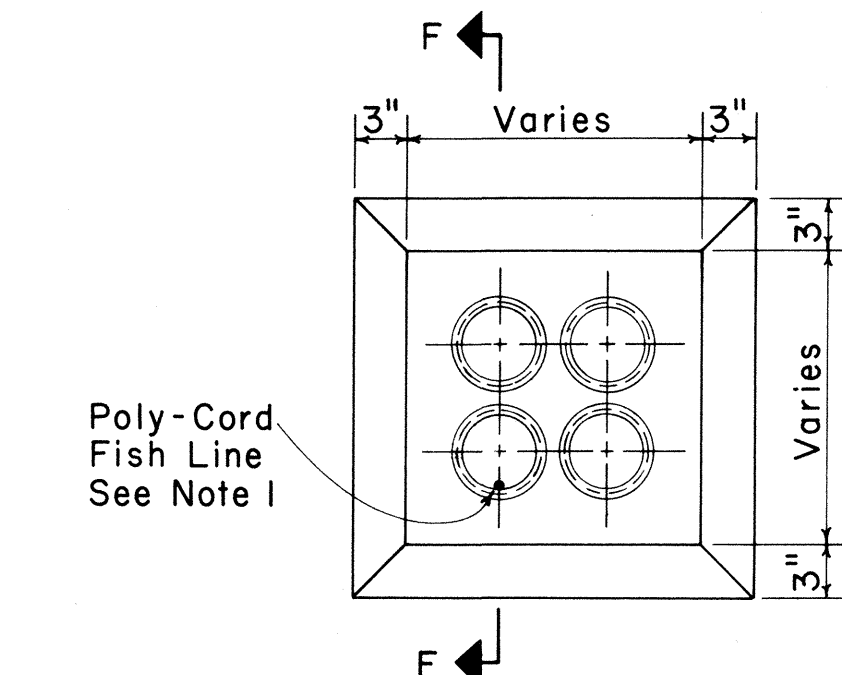


TYPICAL MANHOLE DUCT WINDOW

NOTE:


1. The contractor shall place poly-cord fish line in each duct throughout it's entire length with protrusions of 2 feet in manholes and handholes at each end and 1 foot in pullboxes.

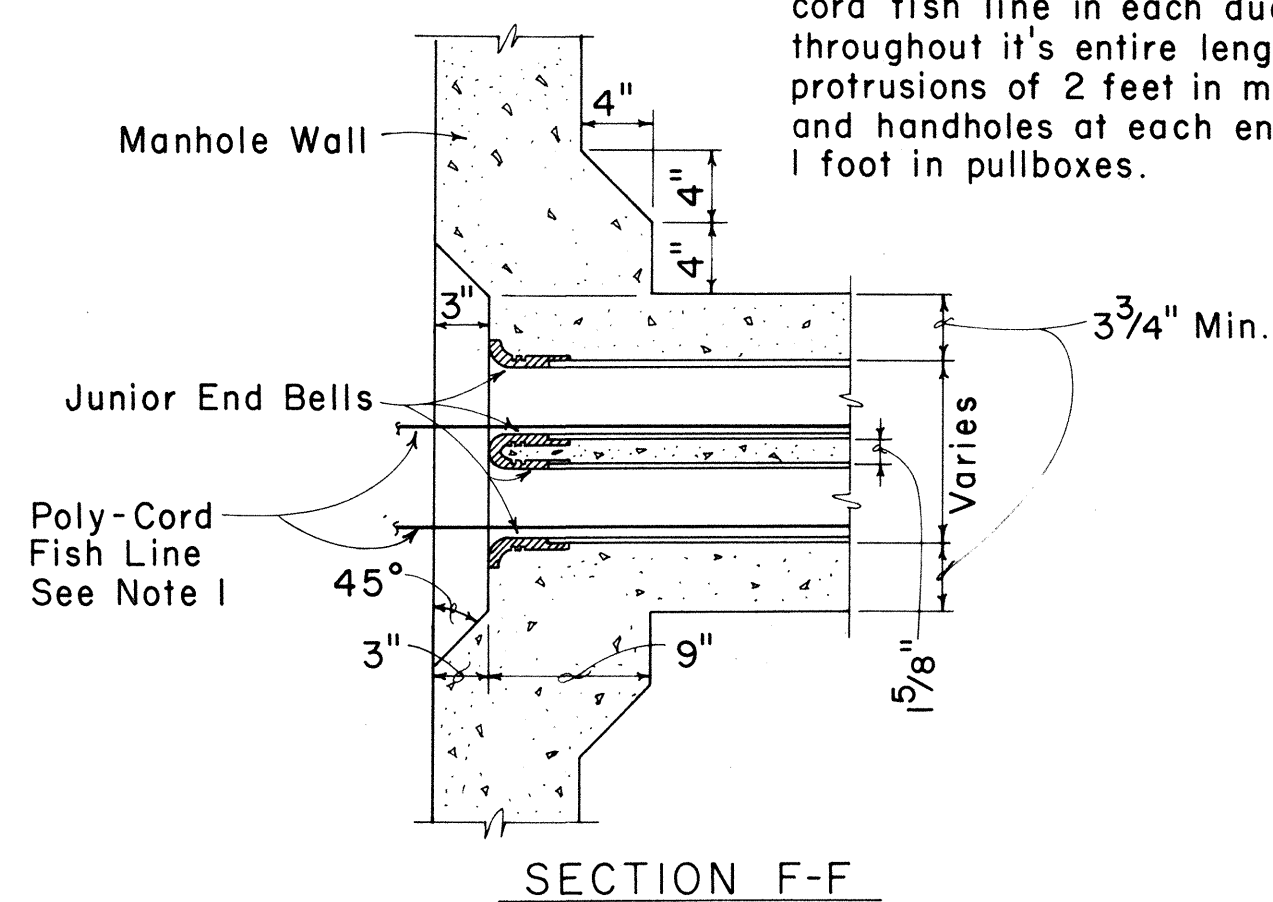


TYPICAL DUCT WINDOW DETAIL
& JUNIOR END BELL

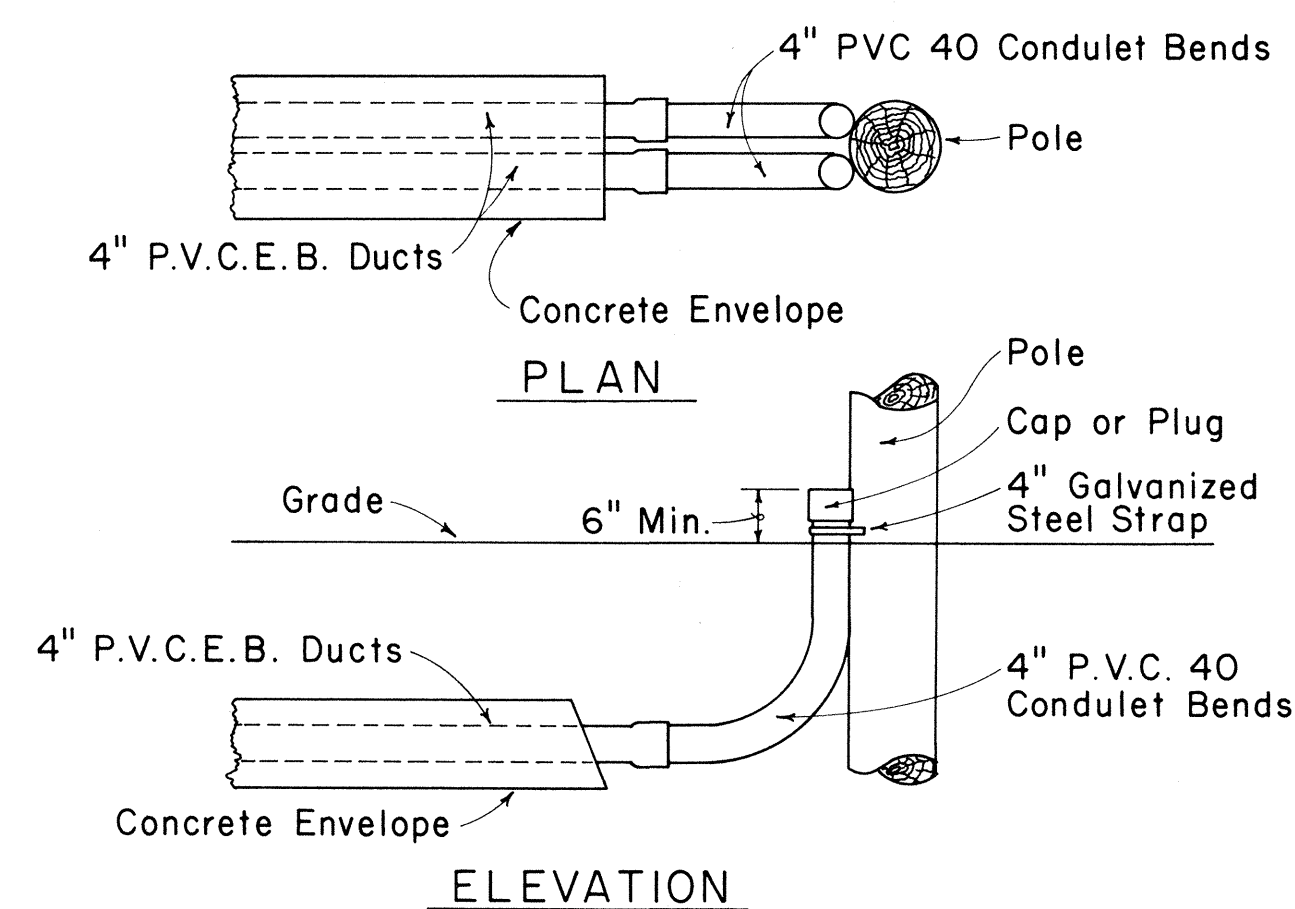


TYPICAL CONDULET BEND INSTALLATION DETAILS

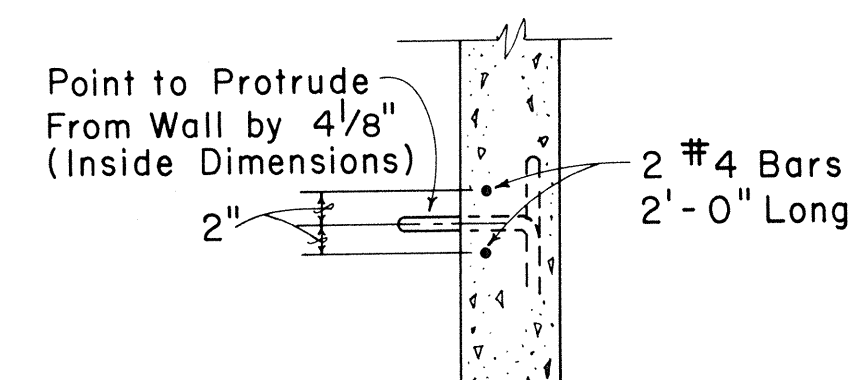


SECTIONAL VIEW
OF PULLING-IN-IRON

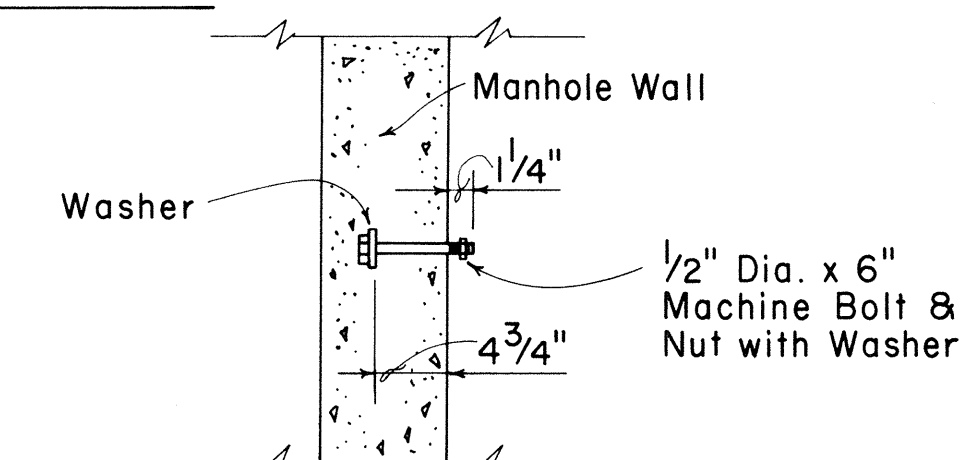

CABLE RACK STUD
BOLT DETAIL

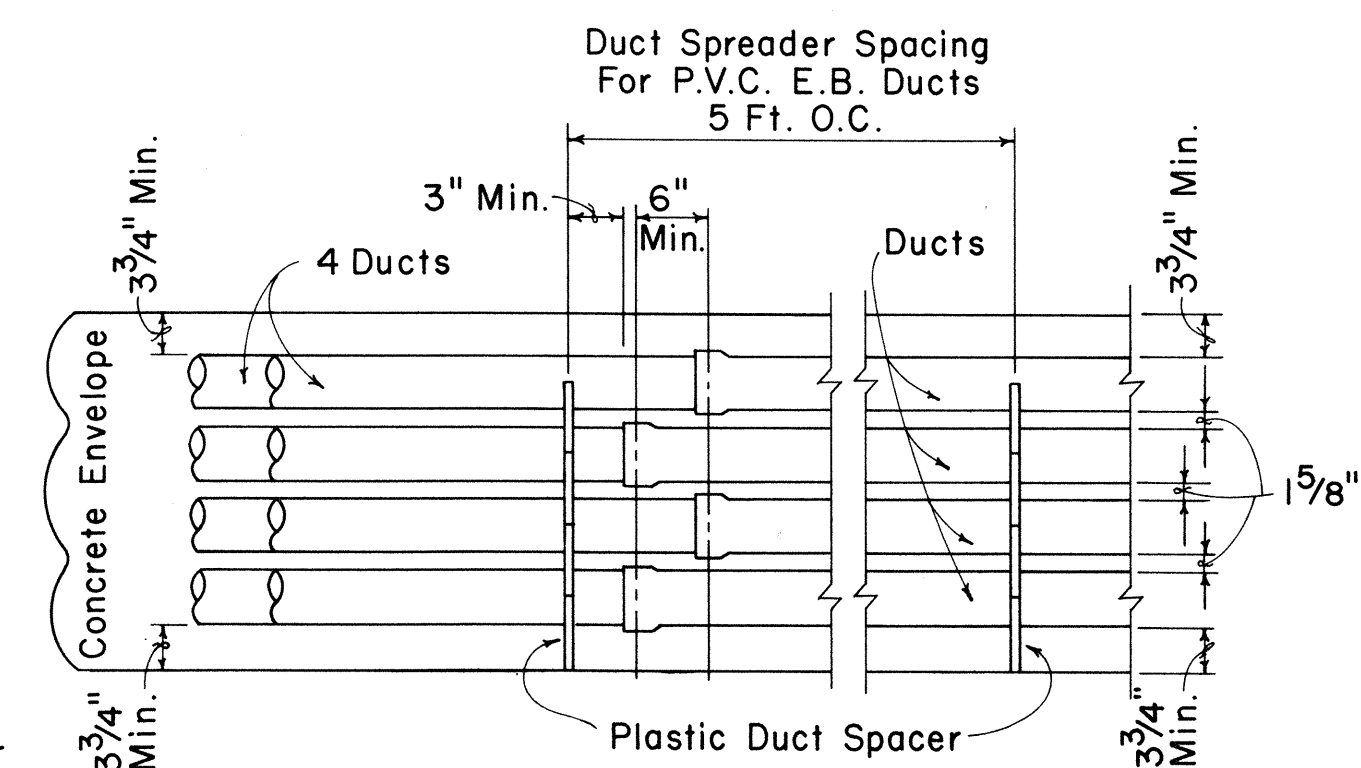


TYPICAL DUCT ENVELOPE ELEVATION
ARRANGEMENT OF PLASTIC SPACERS

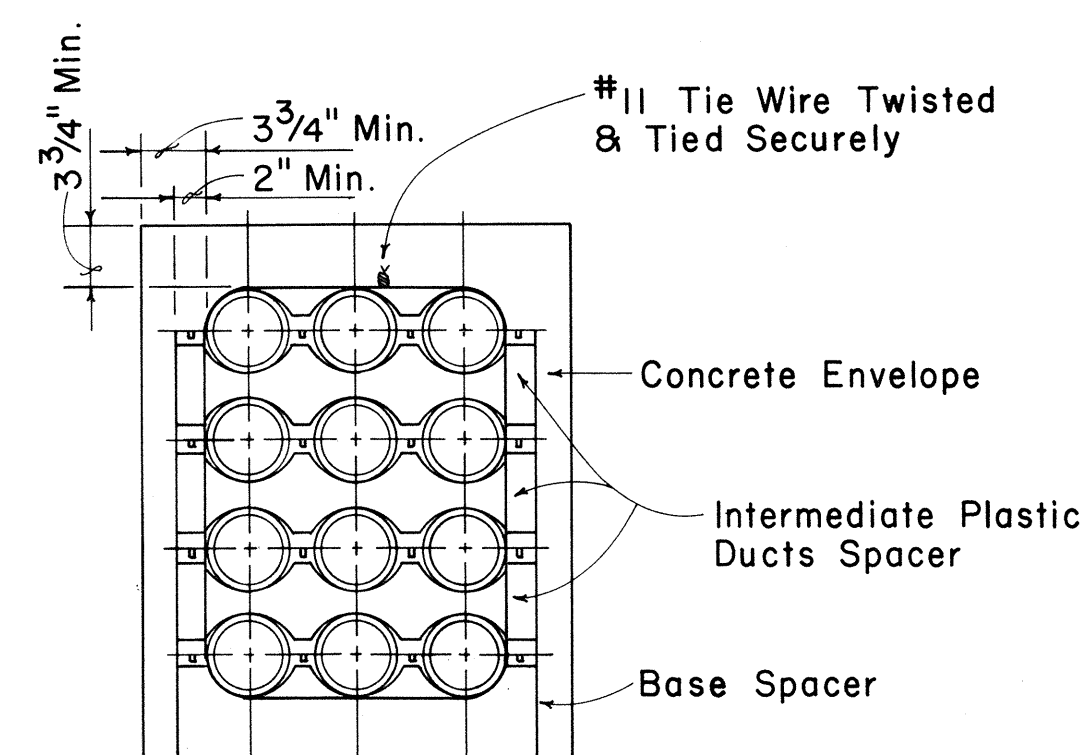

SECTION SHOWING
INTER-LOCKING SPACERS

NOTE

Before placement of concrete contractor shall seal off the crushed rock area with a plastic sheet, to prevent concrete from oozing into 1/4" holes for drainage.

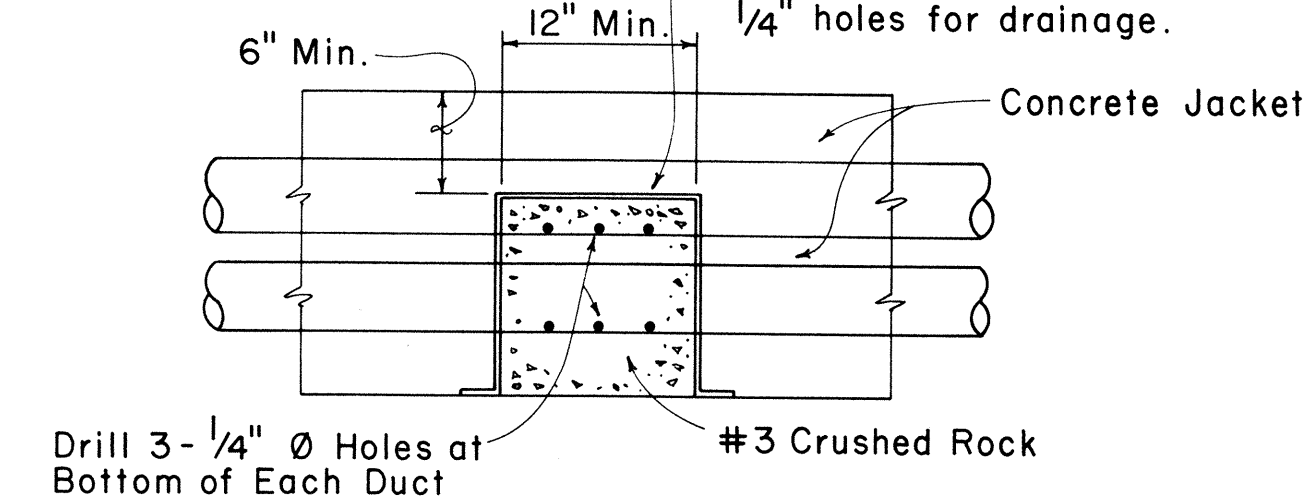

ELEVATION VIEW OF
DUCT DRAIN DETAIL

APPROVED:

Hawaiian Telephone Co., Ltd. 2-12-80
Date

H.T. Co., Ltd. Drawing No. 34028


STATE OF HAWAII
DEPARTMENT OF TRANSPORTATION
LAND TRANSPORTATION FACILITIES DIVISION

STANDARD DUCT FORMATIONS


Not to Scale

SHEET No. 5 OF 8 SHEETS

FED. ROAD DIST. NO.	STATE	FED. AID PROJ. NO.	FISCAL YEAR	SHEET NO.	TOTAL SHEETS
HAWAII	HAW.	M-7600(2)	1980	148	244

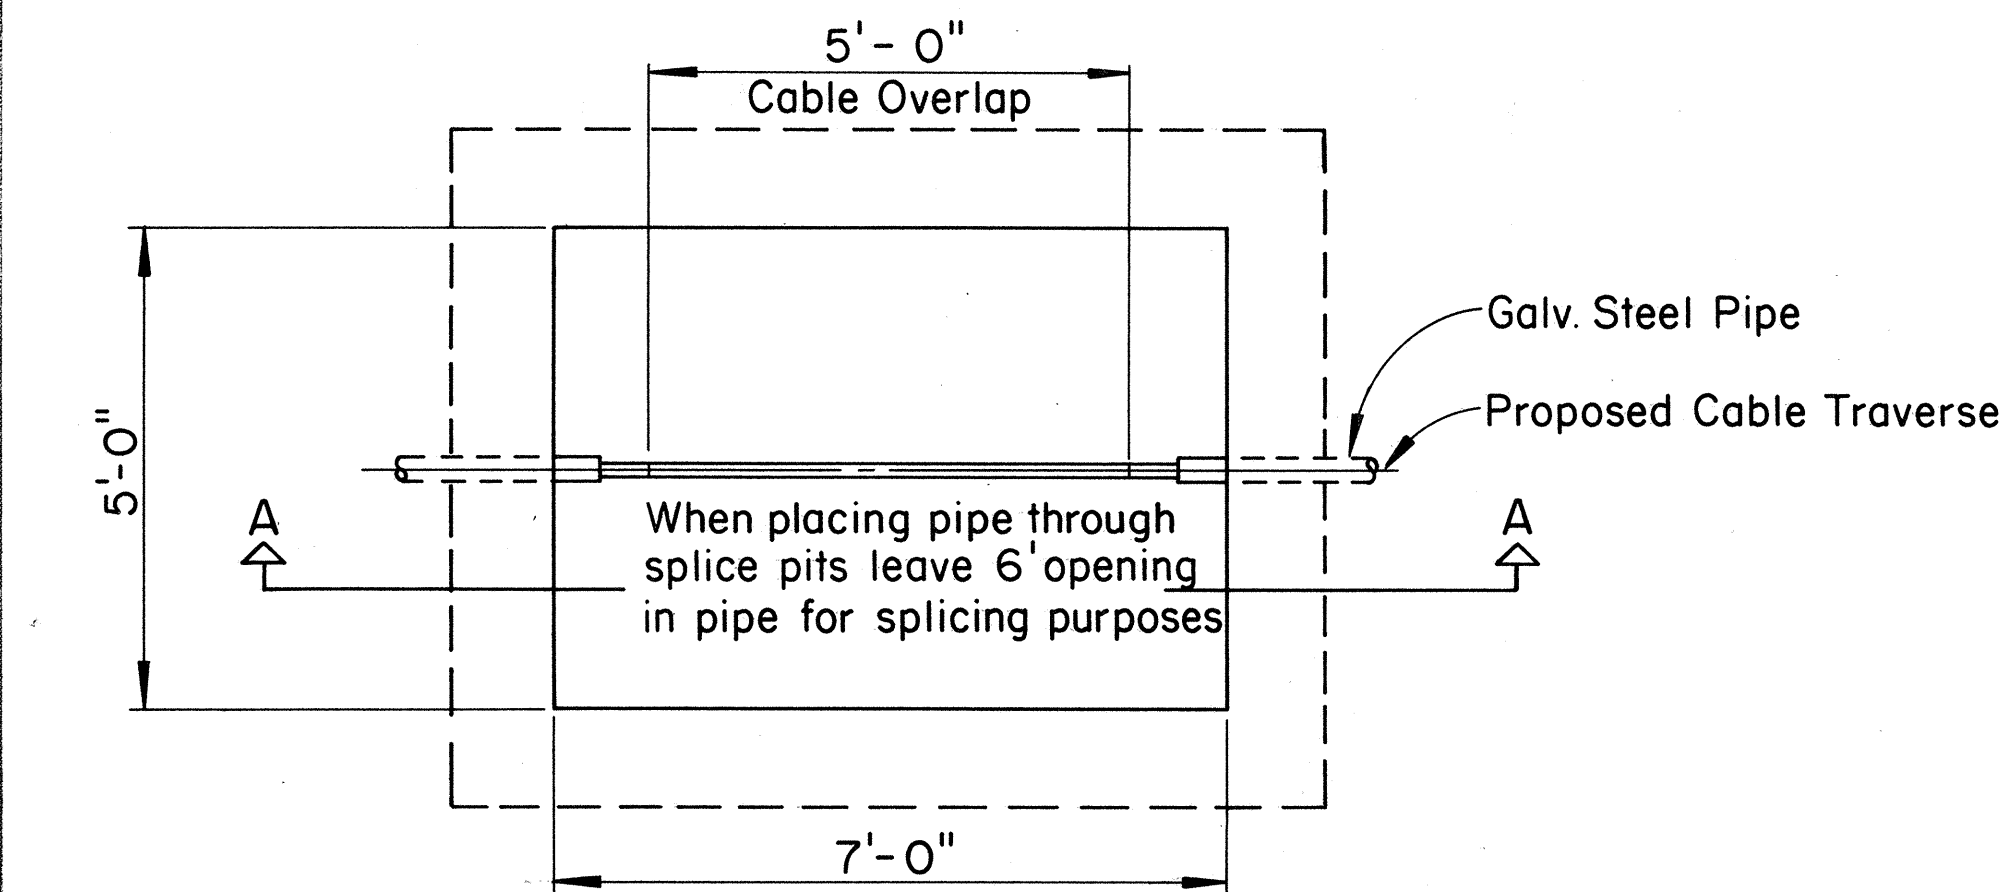

PLAN

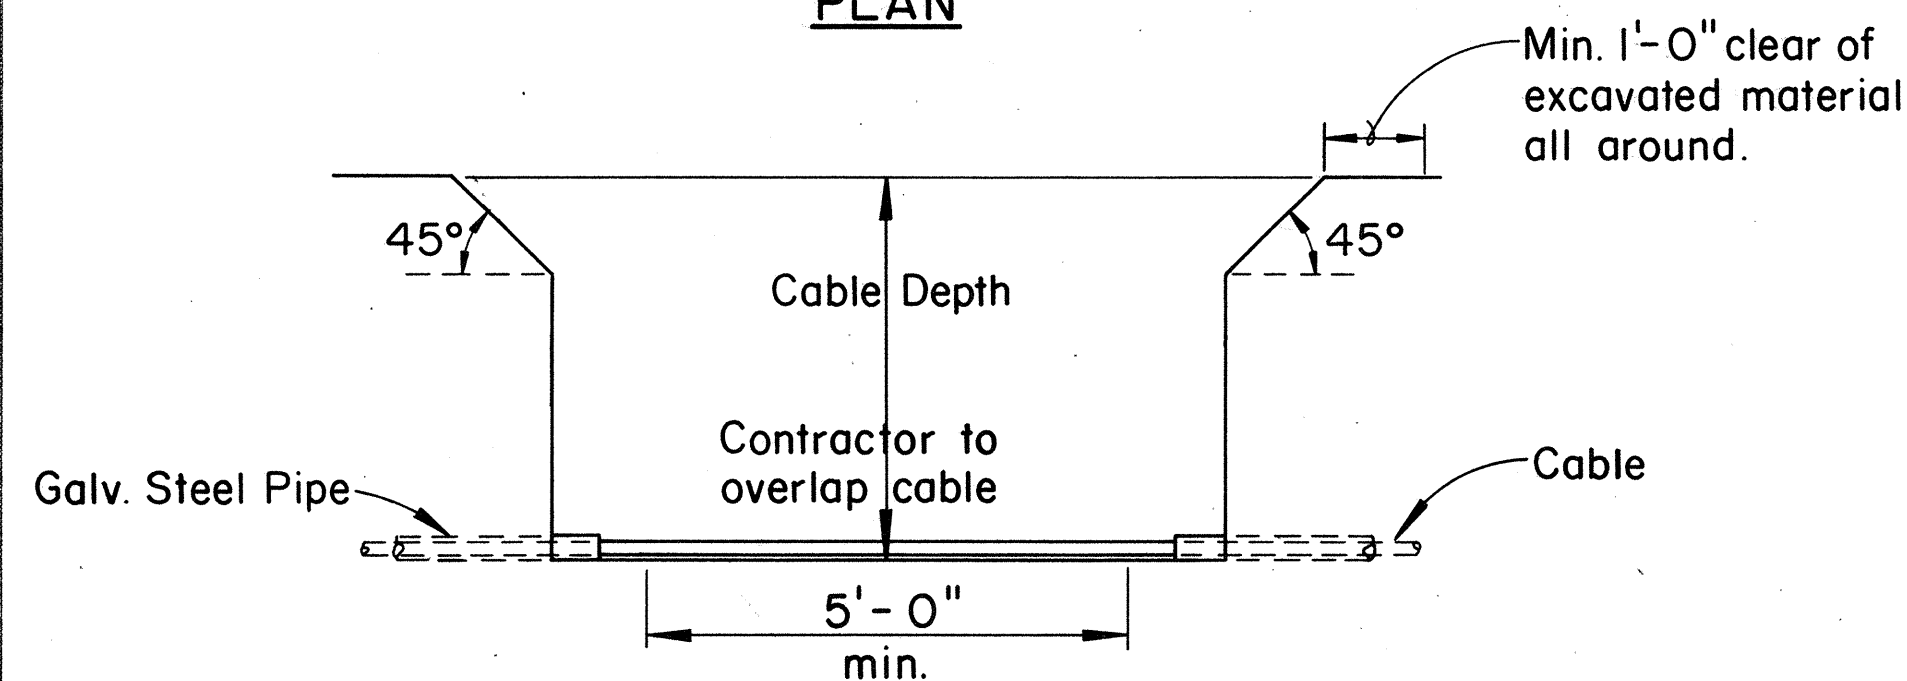


SECTION A-A


TYPICAL SPLICING PITS FOR BURIED CABLE

NOTES:


1. The Contractor shall dig pits at specified locations.
2. One face of pit shall be kept free of excavated material.
3. Where pits are located on sloping or irregular ground, the excavated material shall be placed in such a manner as to prevent surface water from draining into the pit.
4. Provide a fence around the pit at any location where stock have access to the route, and pits near farm homes to keep out small animals and pets.

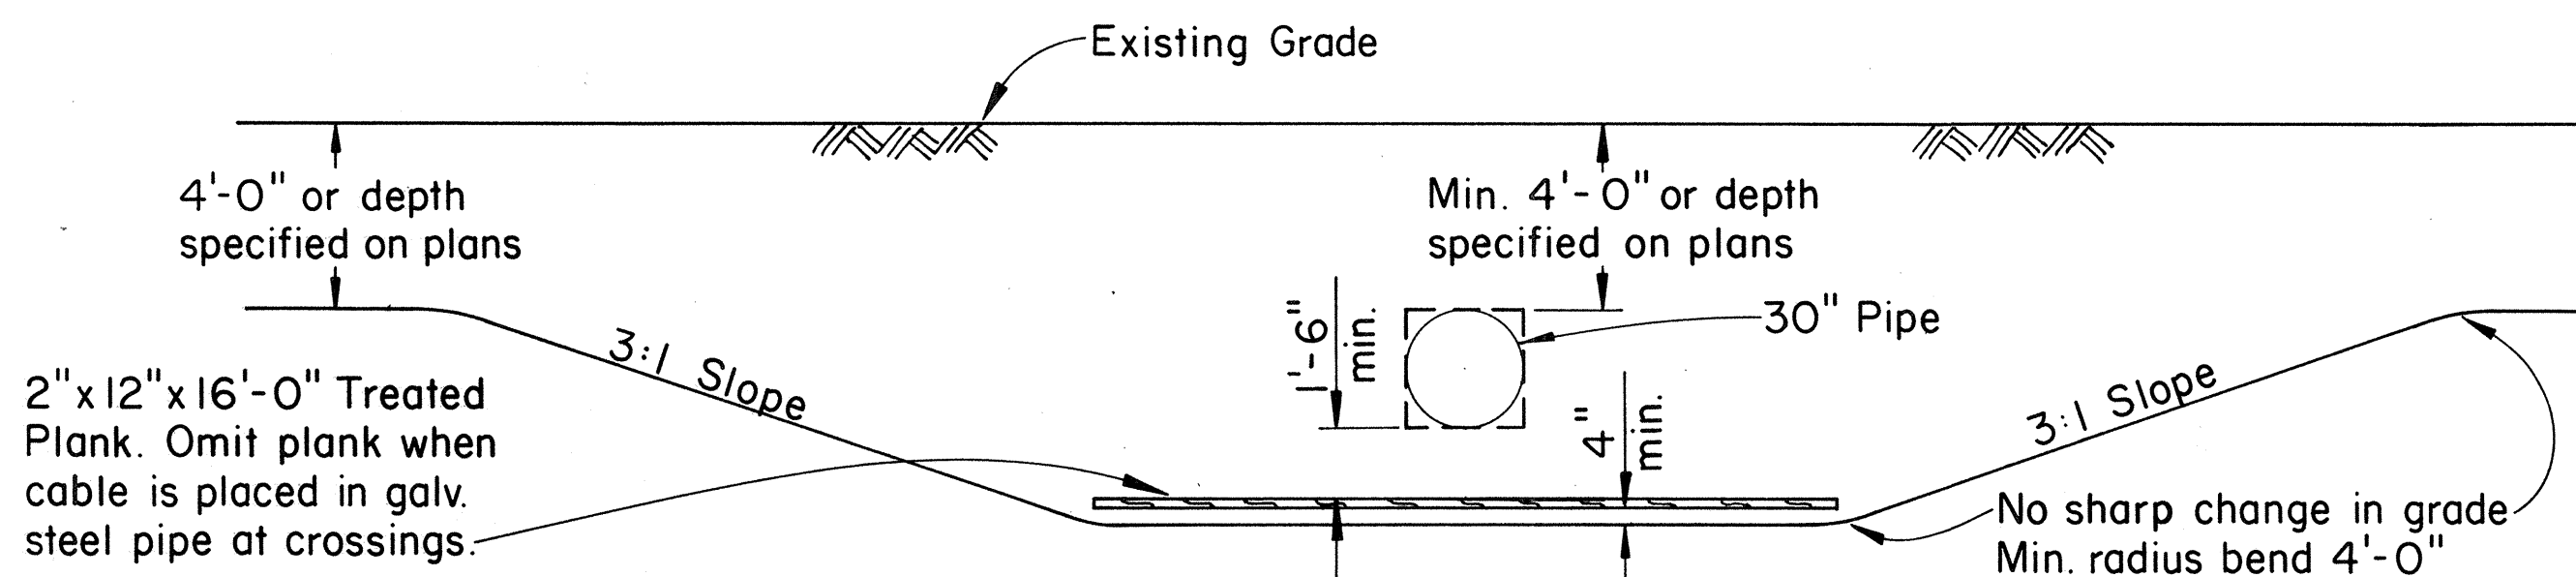


DETAIL OF CABLE CROSSING UNDER STORM CULVERTS-IRRIGATION PIPES, OTHER UTILITIES, OR FOREIGN PIPES

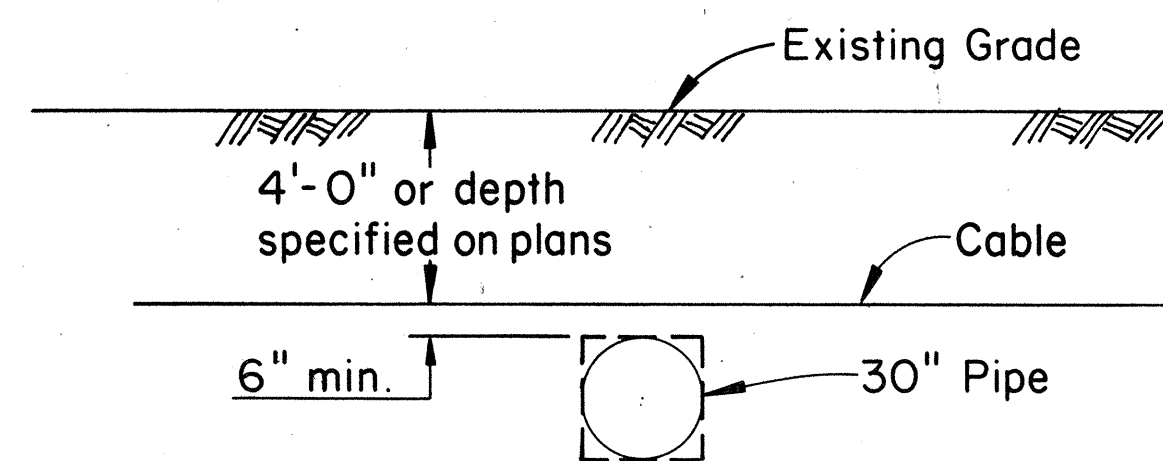


DETAIL OF CABLE CROSSING OVER STORM CULVERTS-IRRIGATION PIPES, OTHER UTILITIES, OR FOREIGN PIPES

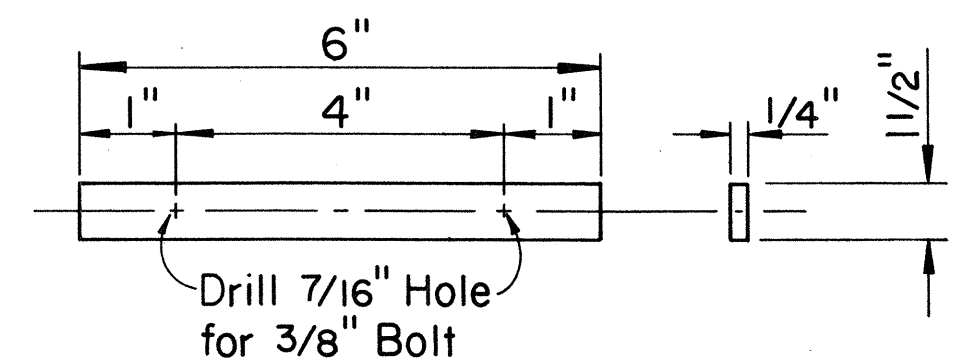

GALVANIZED STRAP DETAIL

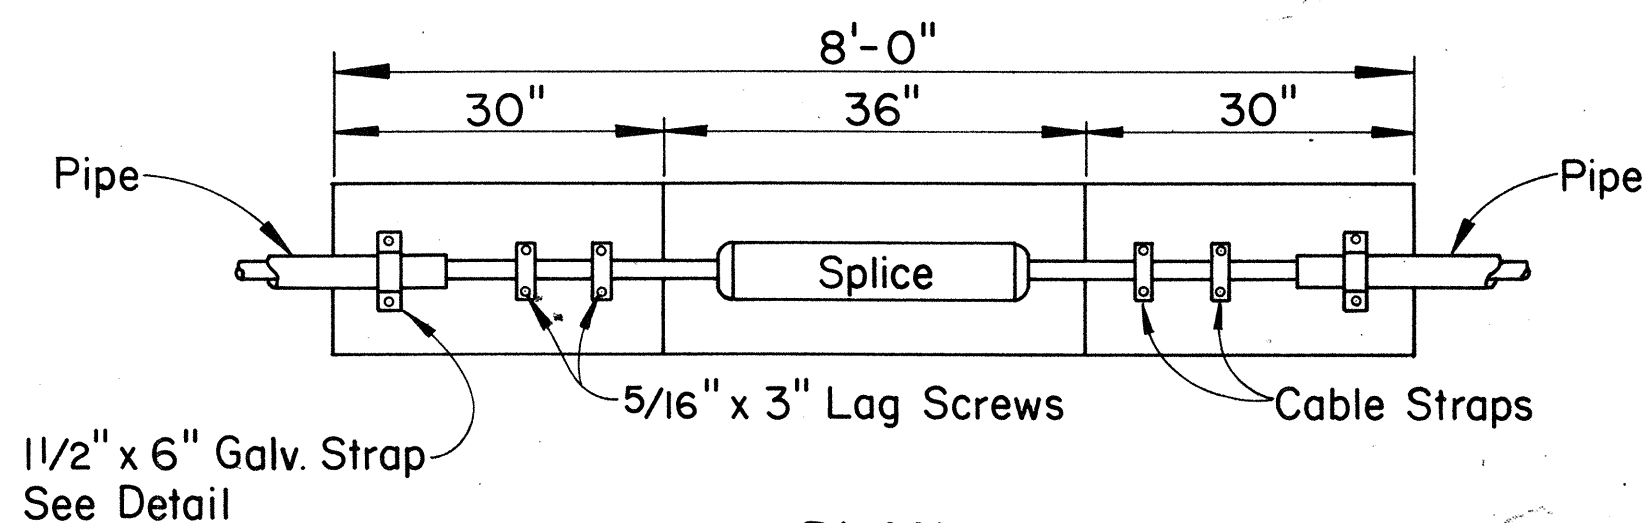


PLAN

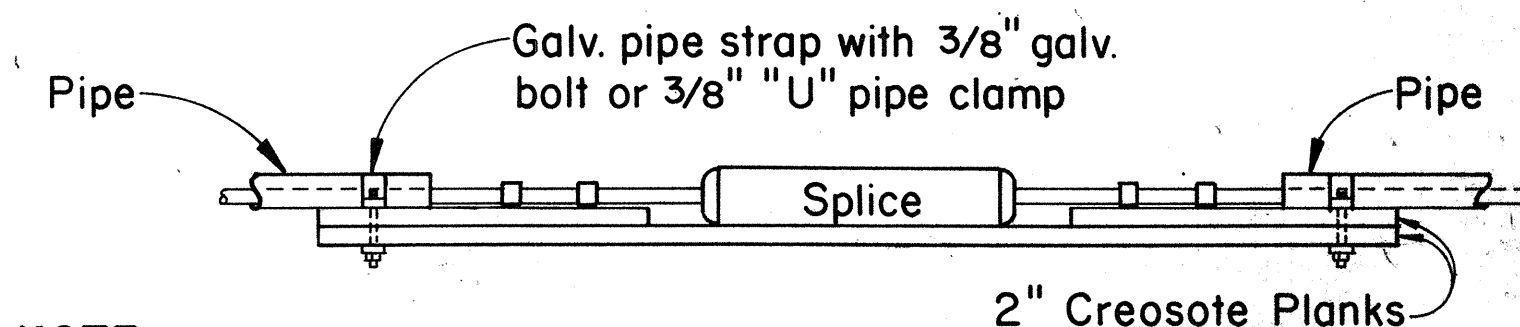


ELEVATION

NOTE:
Galv. Strap may be substituted with pipe clamp.


DETAIL OF SPLICE SUPPORT BETWEEN PIPE SECTIONS

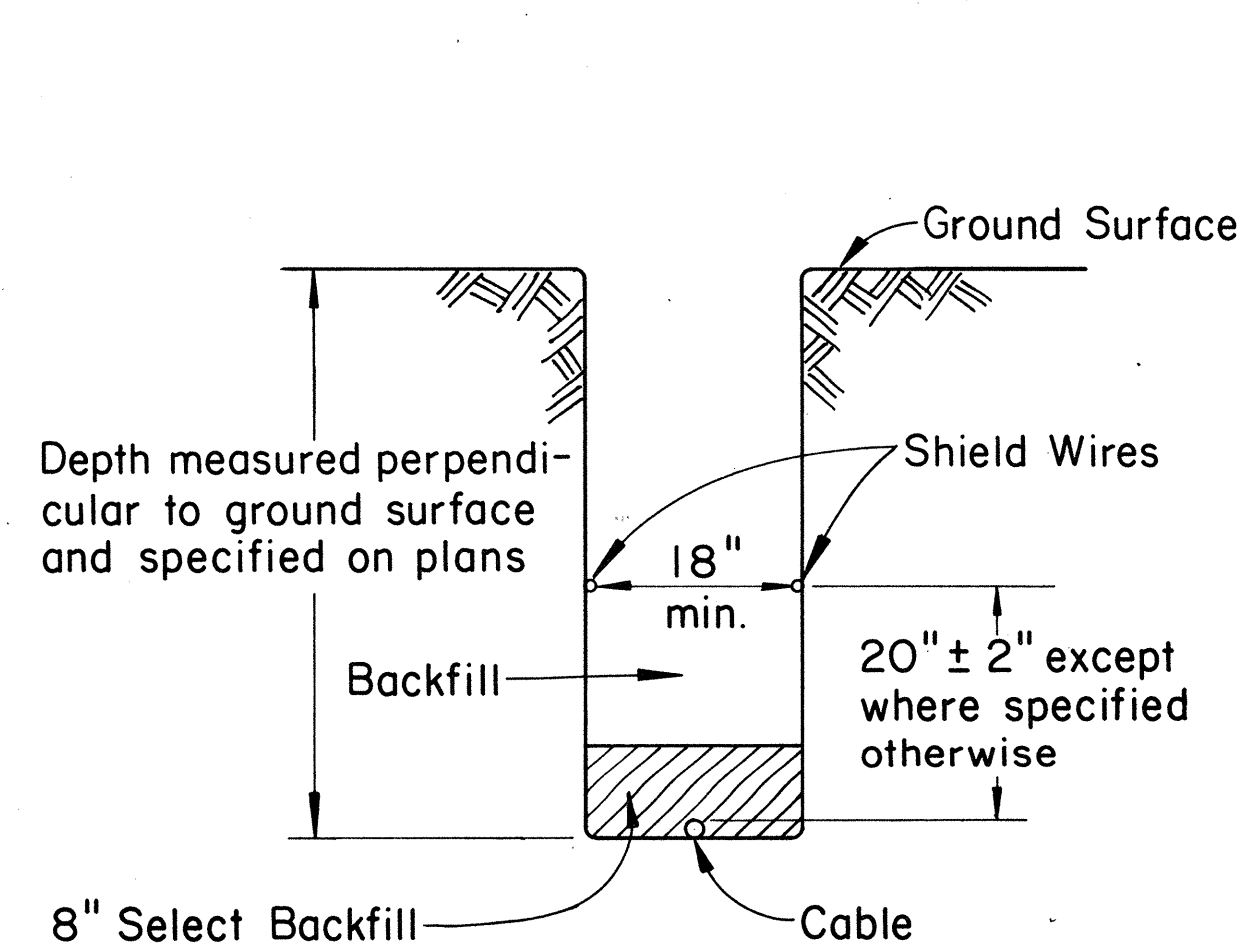


TYPICAL SECTION THROUGH NORMAL TRENCH

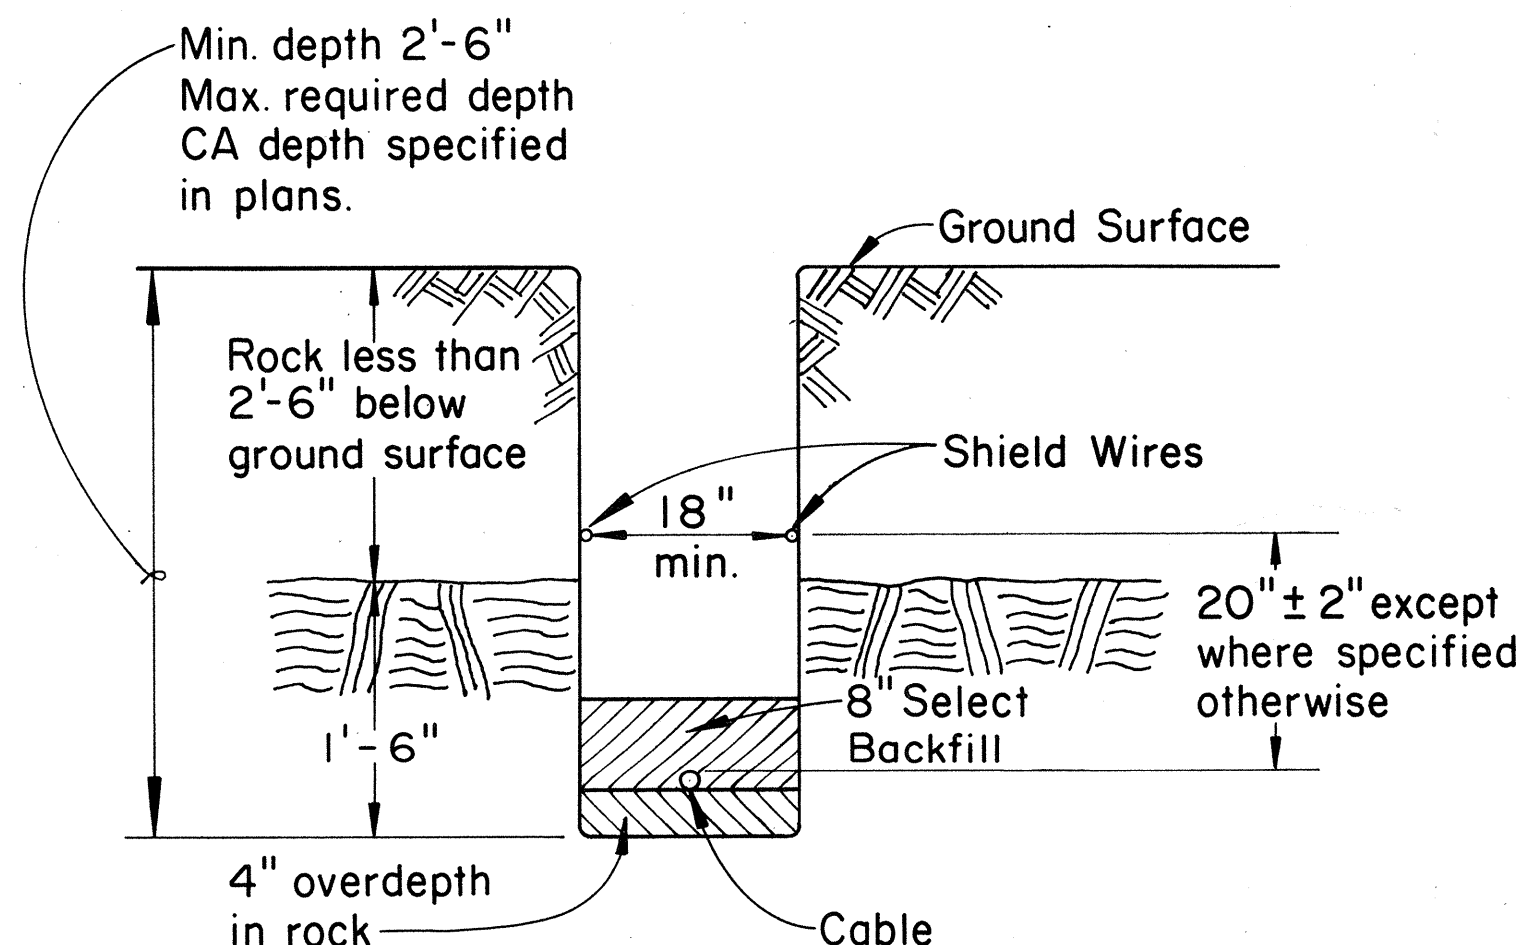

TYPICAL SECTION THROUGH TRENCH WITH ROCK LESS THAN 2'-6" BELOW SURFACE

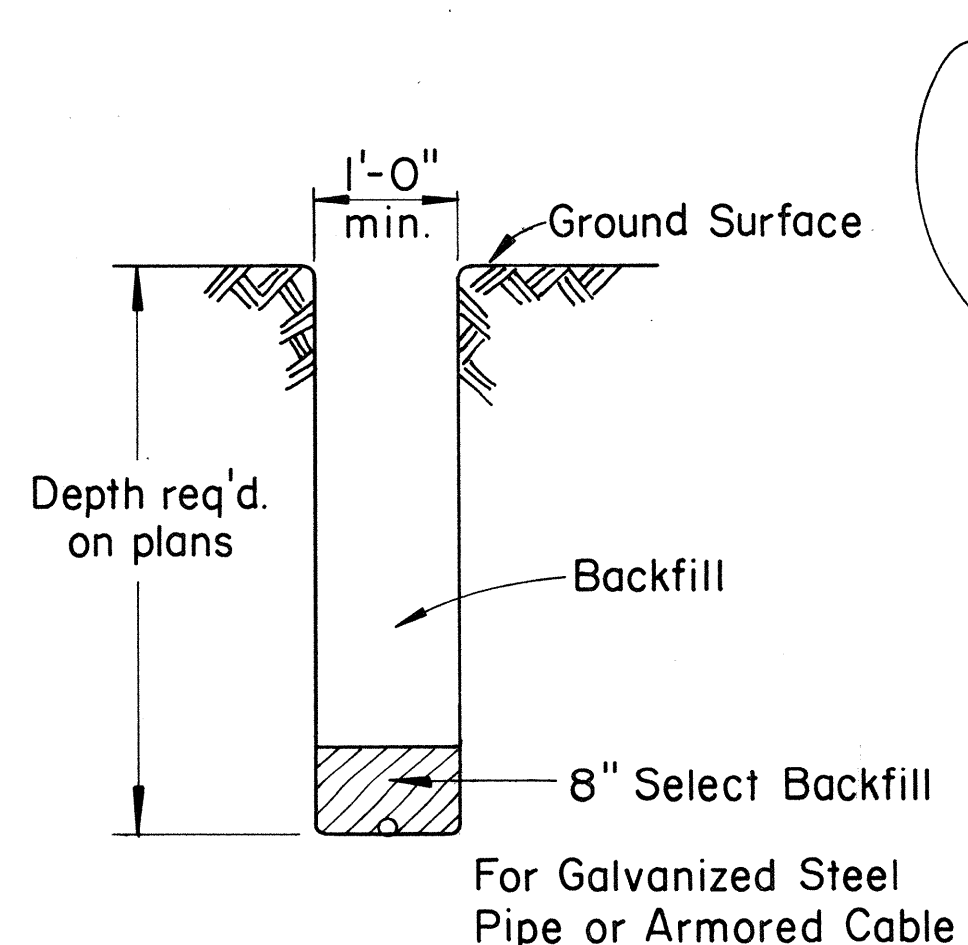

TYPICAL SECTION FOR TRENCH WHERE NO SHIELD WIRE IS REQUIRED

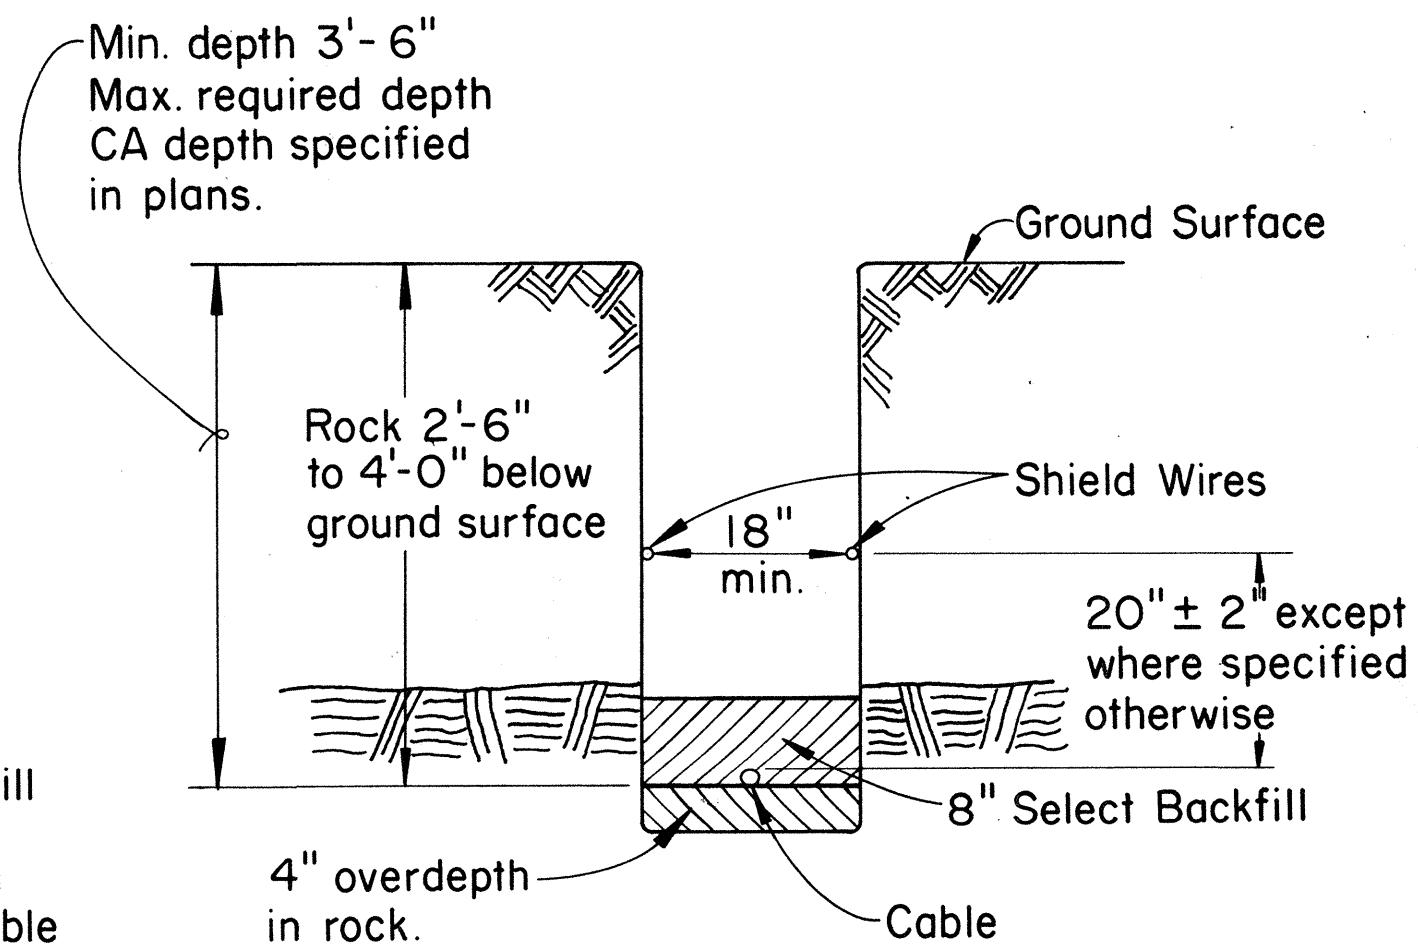

TYPICAL SECTION THROUGH TRENCH WITH ROCK 2'-6" TO 4'-0" BELOW SURFACE

APPROVED:
[Signature]
Hawaiian Telephone Co., Ltd. Date 2-2-80

H.T. Co., Ltd. Drawing Nos. 34047 34048

STATE OF HAWAII
DEPARTMENT OF TRANSPORTATION
HIGHWAYS DIVISION
STANDARD DETAILS
SPLICING PITS AND
STANDARD TRENCHING DETAILS
FOR BURIED COAXIAL CABLE

Scale: Not to Scale
SHEET No. 6 OF 8 SHEETS

SURVEY PLOTTED BY	DATE
DRAWN BY	
DESIGNED BY	
NOTED BY	
CHECKED BY	
NO.	

Diagram illustrating the reinforcement layout for a slab. The overall dimensions are 11'-4" by 6'-4". The layout shows 16 vertical bars (#6 @ 8" O.C.) and 4 horizontal bars (#6 @ 16" O.C.). A central square area is marked with a diamond and a cross, labeled "2" All around". The top and bottom edges are labeled "1'-2"" and "1'-2"" respectively. The left and right edges are labeled "8"" and "8"" respectively.

11' - 4"

5" 19 - #6 @ 7" O.C. = 10' - 6" 5"

Diagonal Reinf.
2 - #5 @ 3" O.C.

2" C.I.

10" 6 - #6 @ 14" O.C. = 4'-8" 10"

Technical drawing of a rectangular plate with a central circular hole. The drawing includes the following dimensions and features:

- Overall Dimensions:**
 - Length: 11'-4"
 - Width: 6'-4"
- Internal Dimensions and Features:**
 - Distance from left edge to center of hole: 2'-0"
 - Distance from center of hole to right edge: 10'-0"
 - Distance from top edge to center of hole: 11'-4"
 - Distance from center of hole to top edge: 10'-0"
 - Distance from center of hole to bottom edge: 10'-0"
 - Distance from center of hole to right edge: 10'-0"
- Other Features:**
 - Central circular hole with diameter ϕ 8'-0"
 - Ground Rod (3/4" ϕ x 8'-0")
 - Labels A, B, C, D, E, F, G, H, I, J, K, L, M, N, O, P, Q, R, S, T, U, V, W, X, Y, Z

#4 "U" Bars @ 20" O.C.
Spaced in between Straight
Bars or "U" Bars

3'-6"
2'-9"

End of #4
"U" Bars
2'-11"

End of #4
"U" Bars
2'-11"

#4 @ 20" O.C. Spaced
in between 4" U Bars

#4 "U" Bars @ 20" O.C.
Spaced in between
#4 "U" Bars

#4 @ 18" O.C.

2 - #4 @ 18" O.C. Each Corner

#4 @ 12" O.C. Vertical Bars

#4 @ 10" O.C.
Alternate Bars
Straight Bars

All reinforcing
symmetrical about CL

#4 Bars @
6" O.C.

#4 @ 18" O.C.
Vertical Bars

1'-6" Lap typical
at each corner

Terminate these Bars 7' below
bottom of roof slab

Diagram illustrating the cross-section of a foundation wall and footing, showing reinforcement details and dimensions.

Reinforcement Details:

- Type "B" Frame & Cover
- Finish Grade Line
- Brick Collar 2" Radius
- #6 Dowel @ 18" O.C.
- #4 "┐" Bars @ 20" O.C. Alternate Bars
- #4 "┐" Bars @ 20" O.C. Alternate Bars
- #4 Vertical Bars @ 18" O.C.
- #4 Vertical Bars @ 12" O.C.
- #4 @ 20" O.C.
- #4 Horizontal Bars @ 6" O.C.
- #6 @ 8" O.C.
- #6 @ 16" O.C.
- #4 Vertical Bent Bars @ 18" O.C.
- #6 @ 14" O.C.
- #6 @ 7" O.C.
- Wall Face
- Window Face
- 3" (multiple locations)
- 2" Cl. (multiple locations)
- 6" (multiple locations)
- 3" (multiple locations)
- 2'-0" (multiple locations)
- 5'-0"
- 8" (multiple locations)
- 8" 3'-0" Max.
- 3/4" φ X 8'-0" Ground Rod

Dimensions:

- 7'-0"
- 8"
- 1'-6"
- 5"
- 2'-0"
- 5'-0"
- 8"
- 8"
- 8" 3'-0" Max.

Labels:

- typical corner
- below

This technical drawing illustrates the cross-section of a foundation wall, detailing its construction and reinforcement. The wall has a total height of 7'-0" and a thickness of 8". A brick collar is shown at the top, which is part of a Type "B" Frame & Cover assembly. The finish grade line is indicated above the collar.

The reinforcement includes:

- #6 bars at 7" O.C. near the top.
- #6 bars at 14" O.C. below the top layer.
- #4 bars at 18" O.C. running vertically through the wall.
- #4 vertical bent bars at 18" O.C. along the bottom edge.
- #4 horizontal bars at 6" O.C. near the base.
- #4 vertical bars at 18" O.C. near the base.
- #4 "L" Bars at 20" O.C. Alternate Bars.
- #4 "U" Bars at 20" O.C. Alternate Bars.

A slope to sump with concrete fill is specified above the slab thickness. Section cut symbols C-C and E-E are provided for further details. Dimensions include 1'-6" for the top section, 7'-0" for the main wall height, 8" for the wall thickness, and 3'-0" Max. for the bottom section. A 3/4" diameter ground rod is also shown.

[illegible]

Scale: _____

Manhole Classification

Width & Length Designation "3" = 5.0' x 10.0'

Manhole Headroom

TYPE "A-3"-7.5'

8.0

8.5

9.0

9.5


10.0

APPROVED: _____


G Yamada
Hawaiian Telephone Co., Ltd.

49


FED. ROAD DIST. NO.	STATE	FED. AID PROJ. NO.	FISCAL YEAR	SHEET NO.	TOTAL SHEETS
HAWAII	HAW.	M-7600(2)	1980	150	244

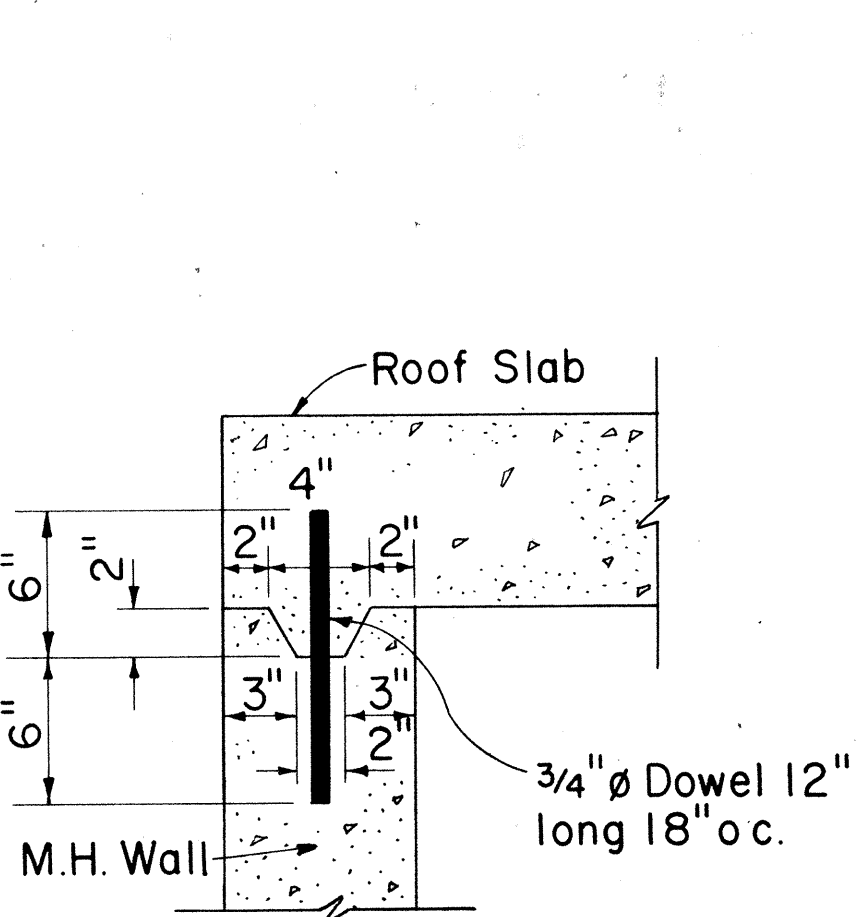


DETAIL "A"
TOP CONSTRUCTION JOINT
Scale: 1 1/2" = 1'-0"
(Optional for cast-in-place construction)
Required for precast construction

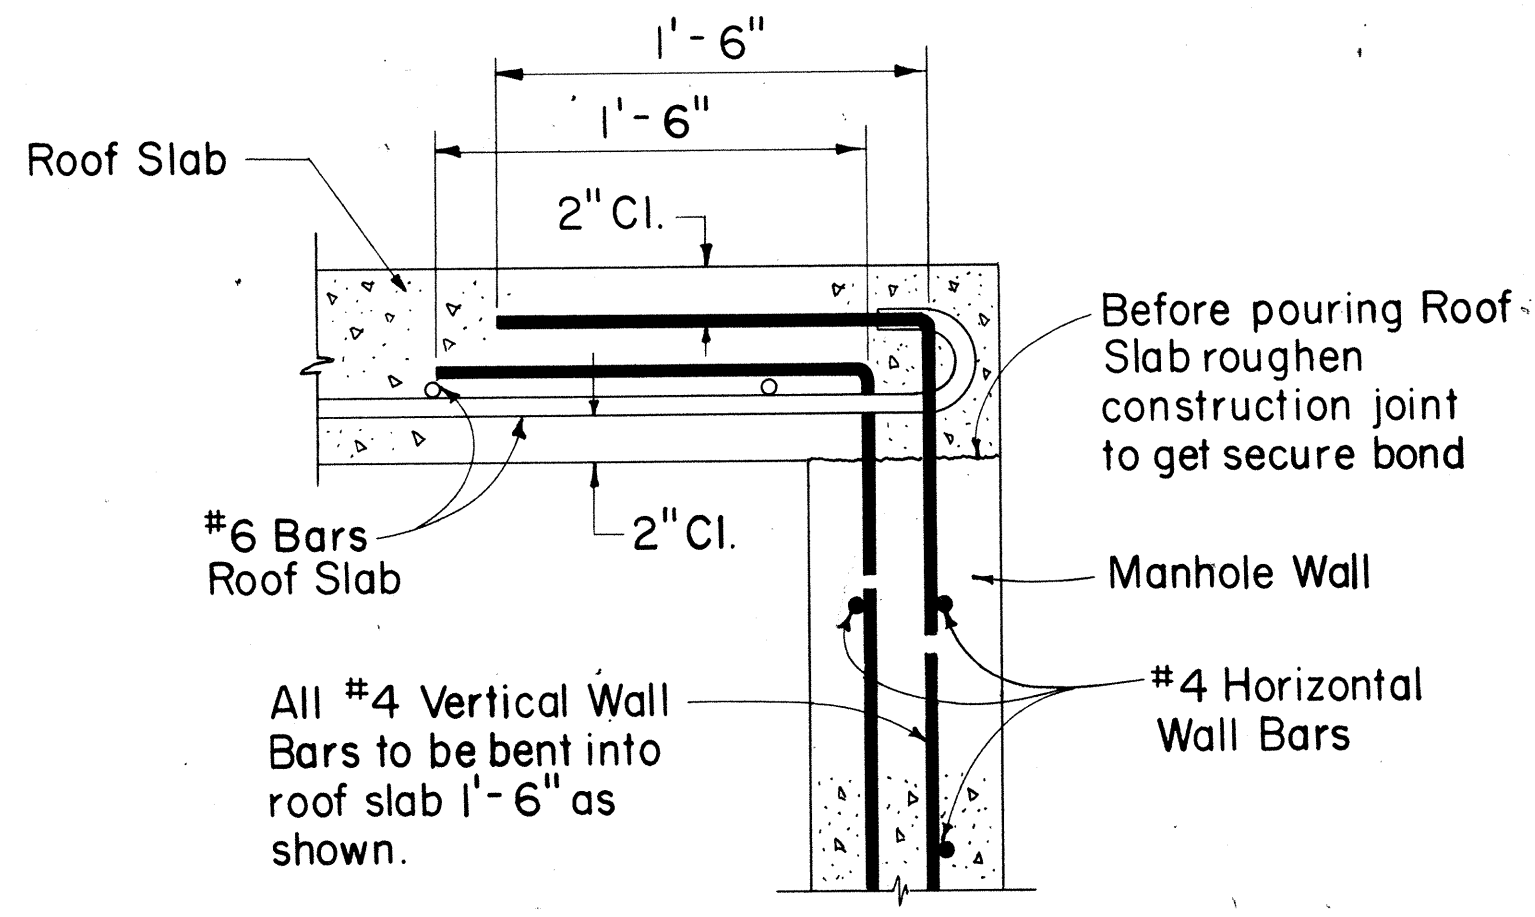


DETAIL "B"
(USED FOR CAST-IN-PLACE CONSTRUCTION)
Scale: 1 1/2" = 1'-0"

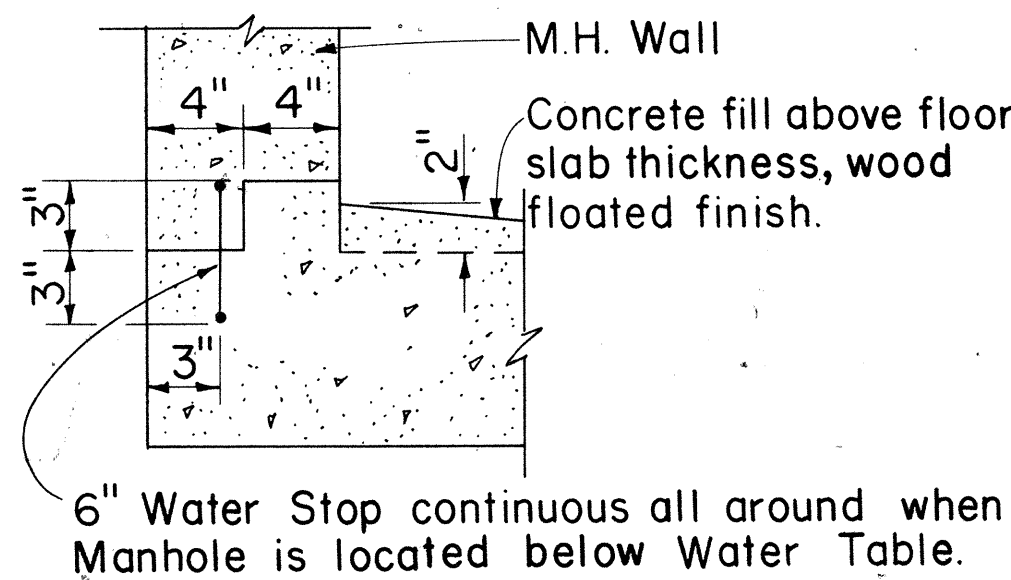


DETAIL "C"
BOTTOM CONSTRUCTION JOINT
Scale: 1 1/2" = 1'-0"

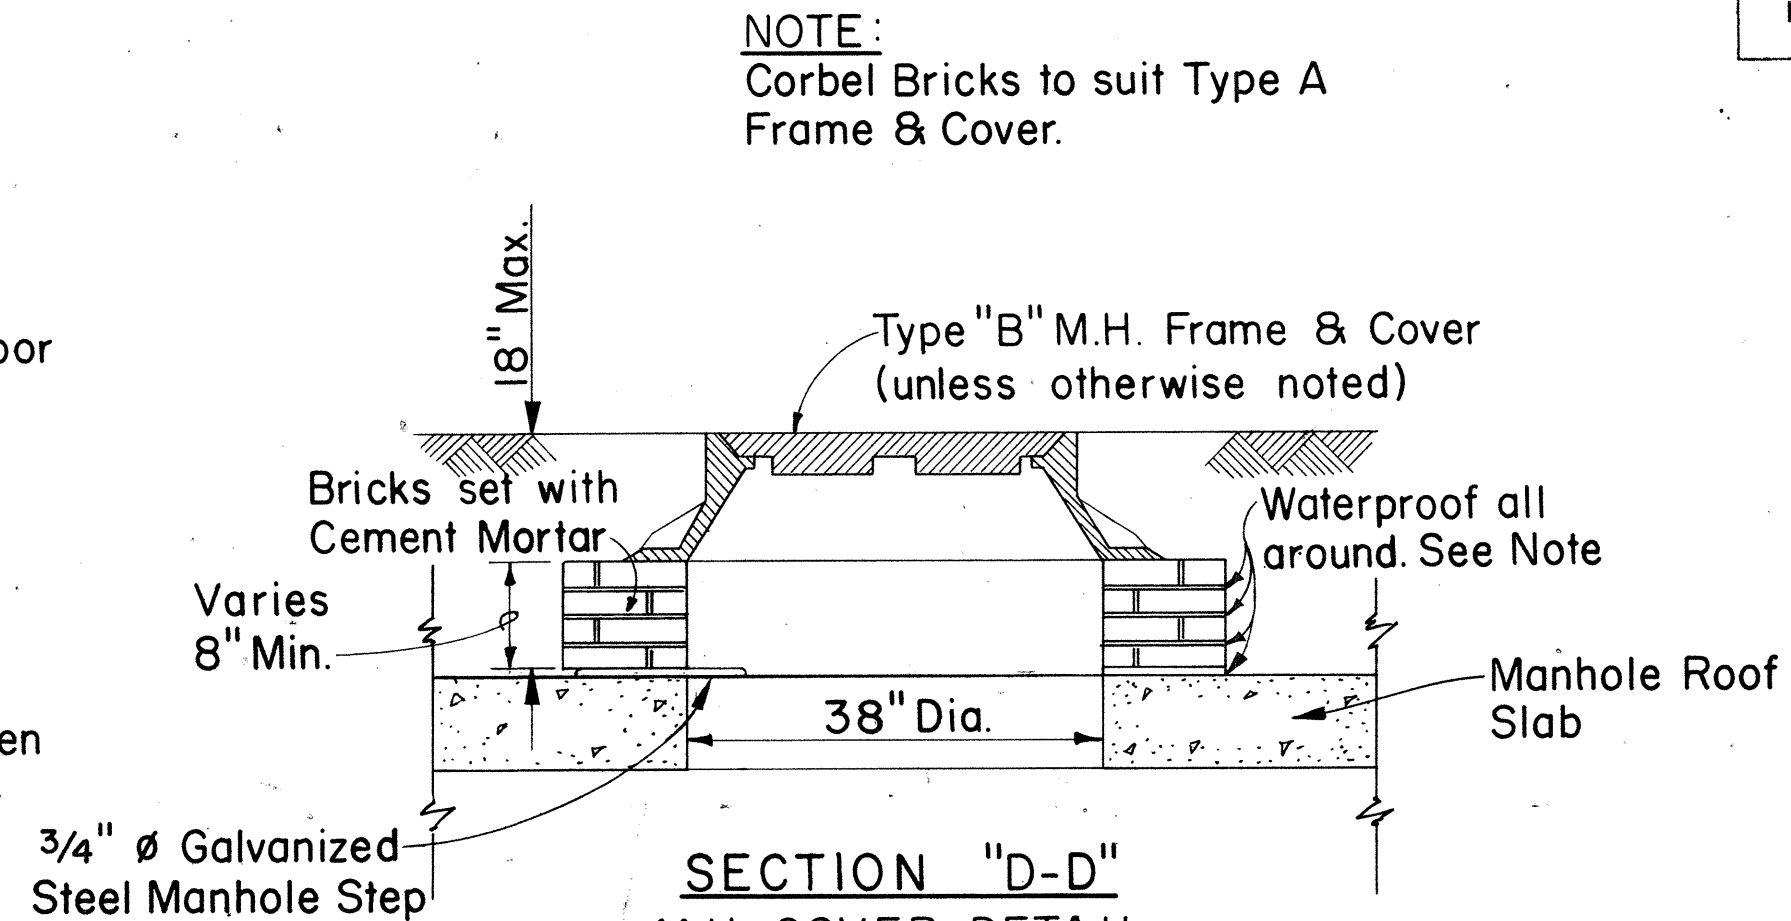


SECTION "D-D"
M.H. COVER DETAIL
Scale: 3/4" = 1'-0"

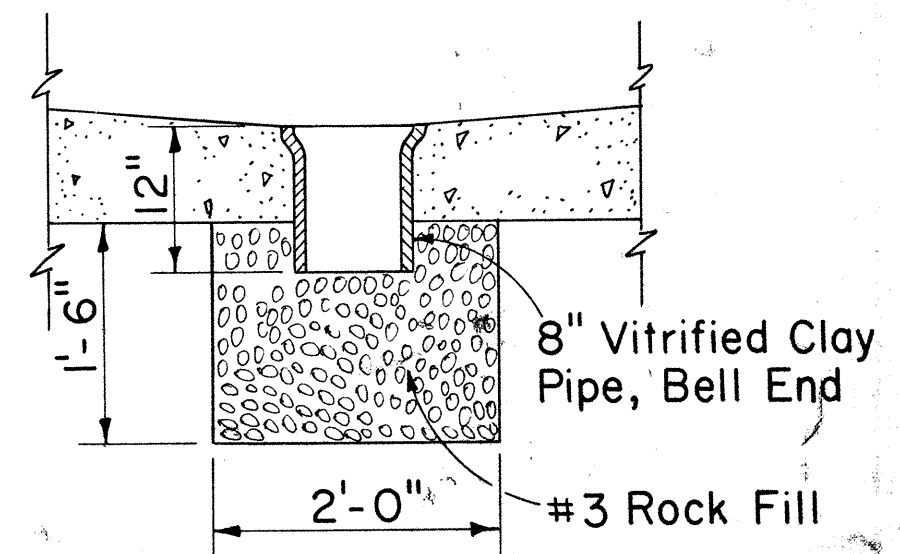


SECTION "E-E"
M.H. SUMP DETAIL
Scale: 3/4" = 1'-0"
Note: See Section "E₁-E₁" Below

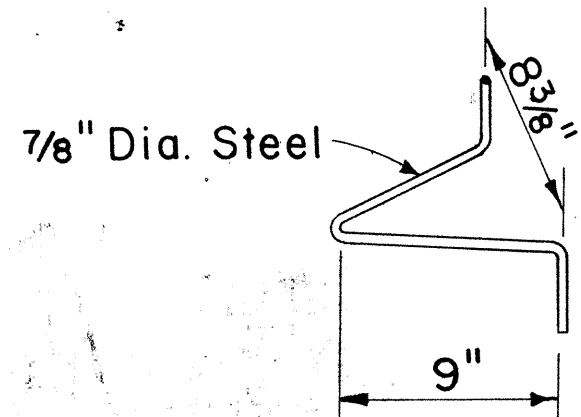


PULLING-IN IRON

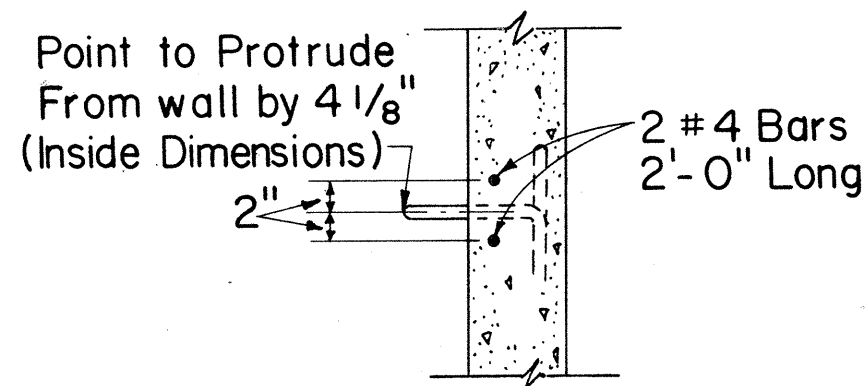


SECTIONAL VIEW OF PULLING-IN IRON
Scale: 3/4" = 1'-0"

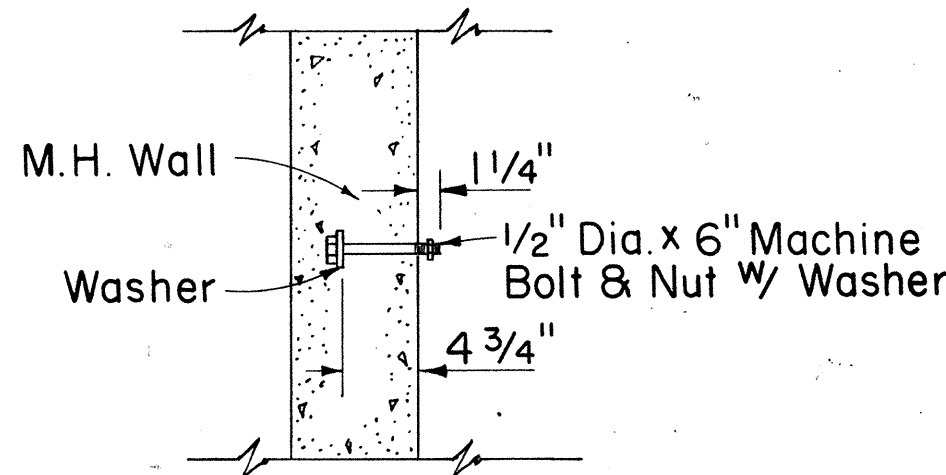

CABLE RACK STUD BOLT DETAIL
Scale: 1" = 1'-0"

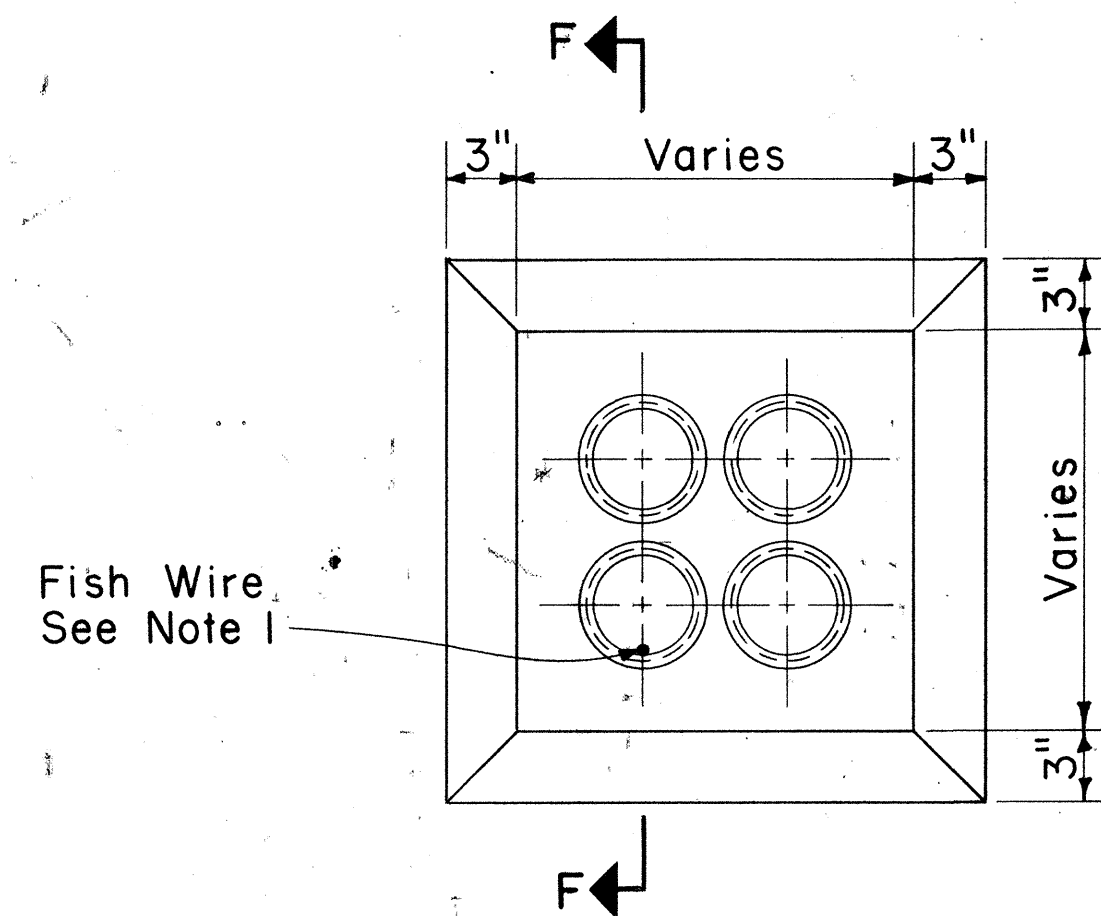


TYPICAL MANHOLE DUCT WINDOW
Scale: 1 1/2" = 1'-0"

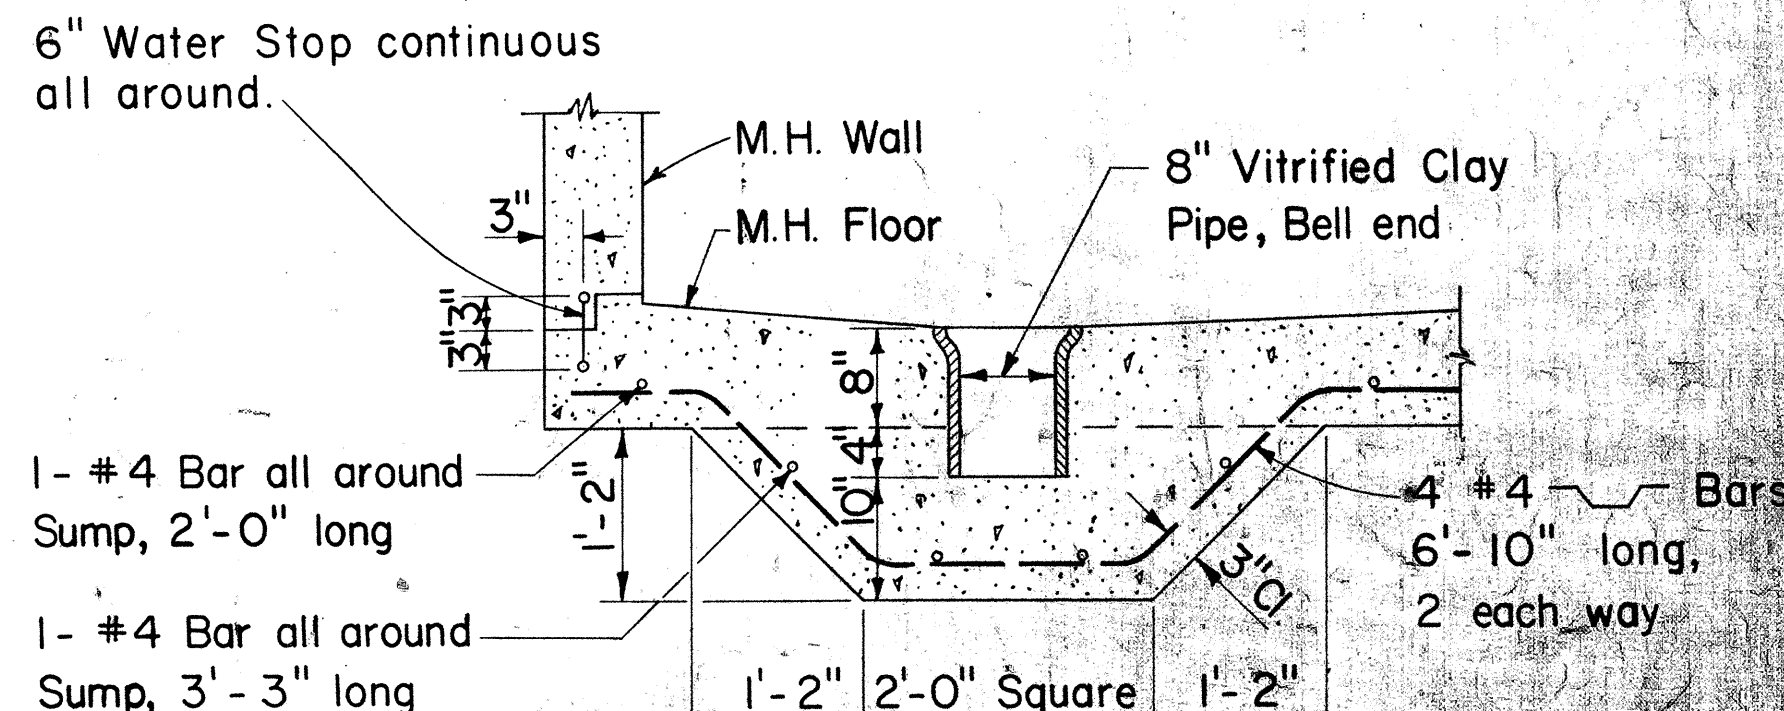


Note: Only for manholes located below water table


SECTION "E₁-E₁"
MANHOLE SUMP DETAIL
Scale: 3/4" = 1'-0"

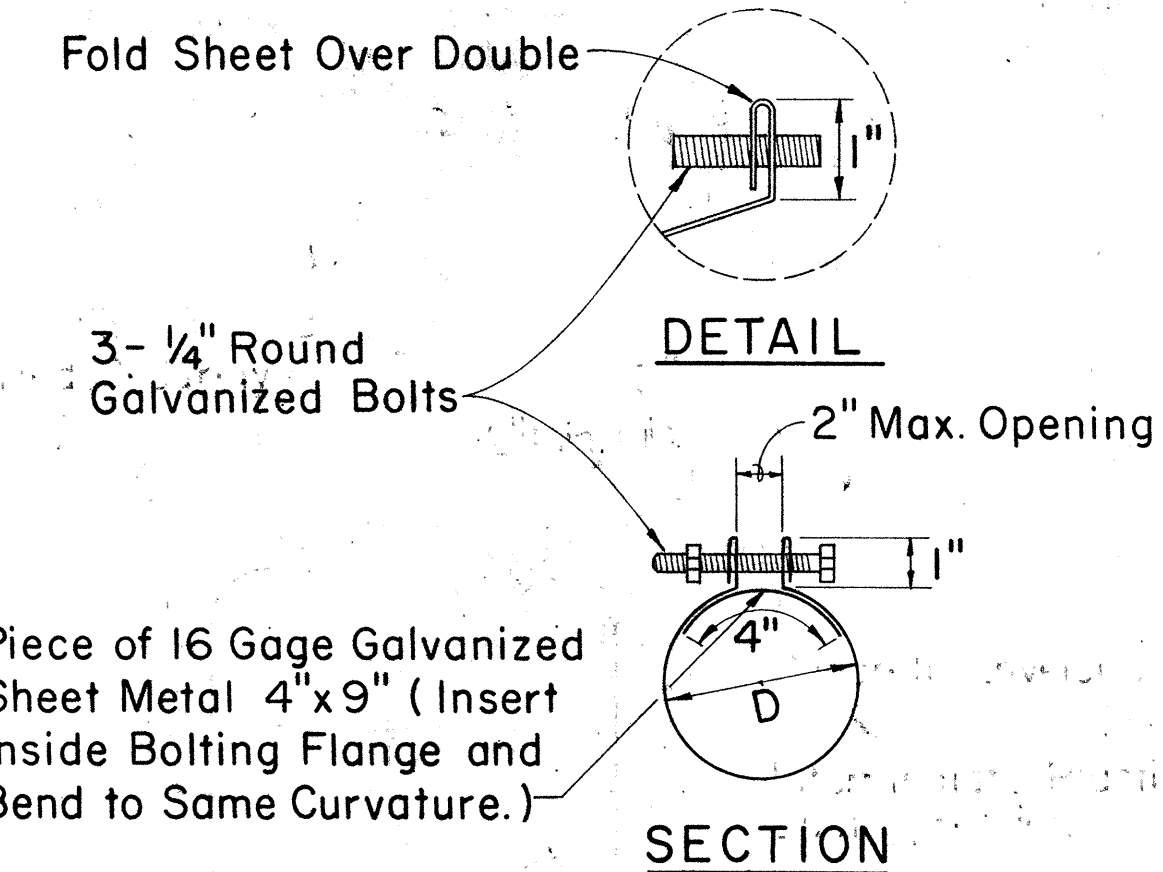


DETAIL SECTION

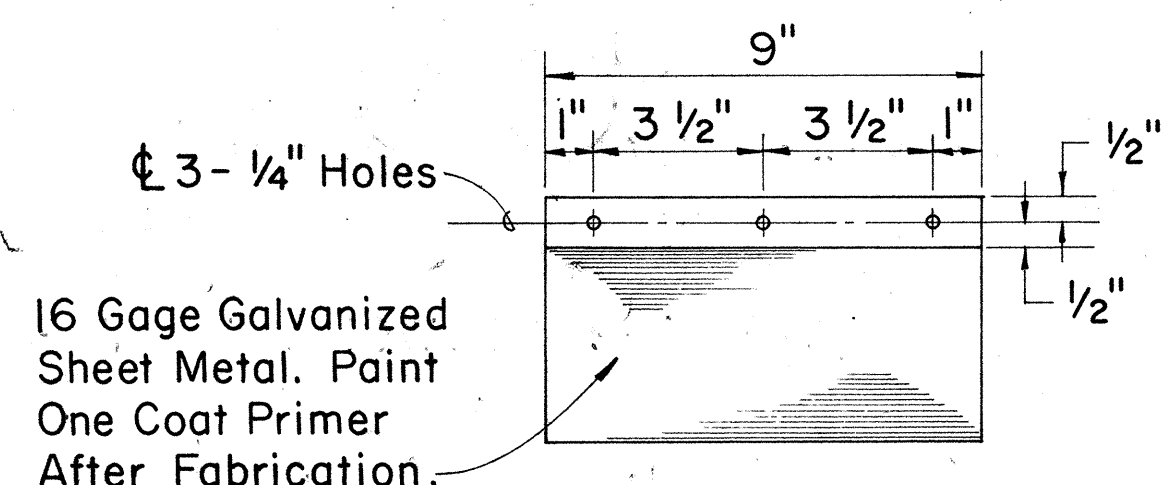


ELEVATION
3-BOLT CLAMP ADAPTOR DETAIL
Scale: 3" = 1'-0"

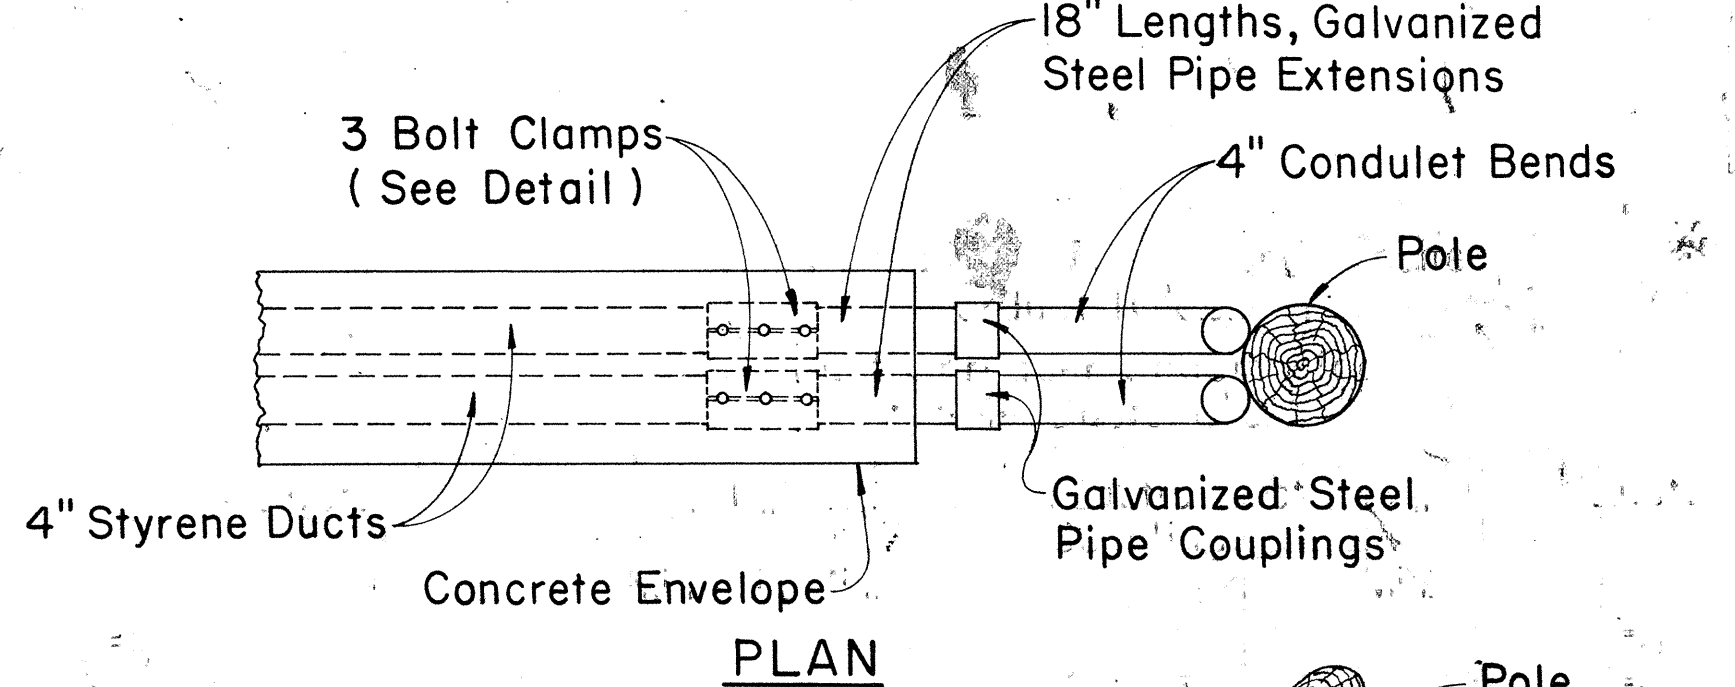


PLAN

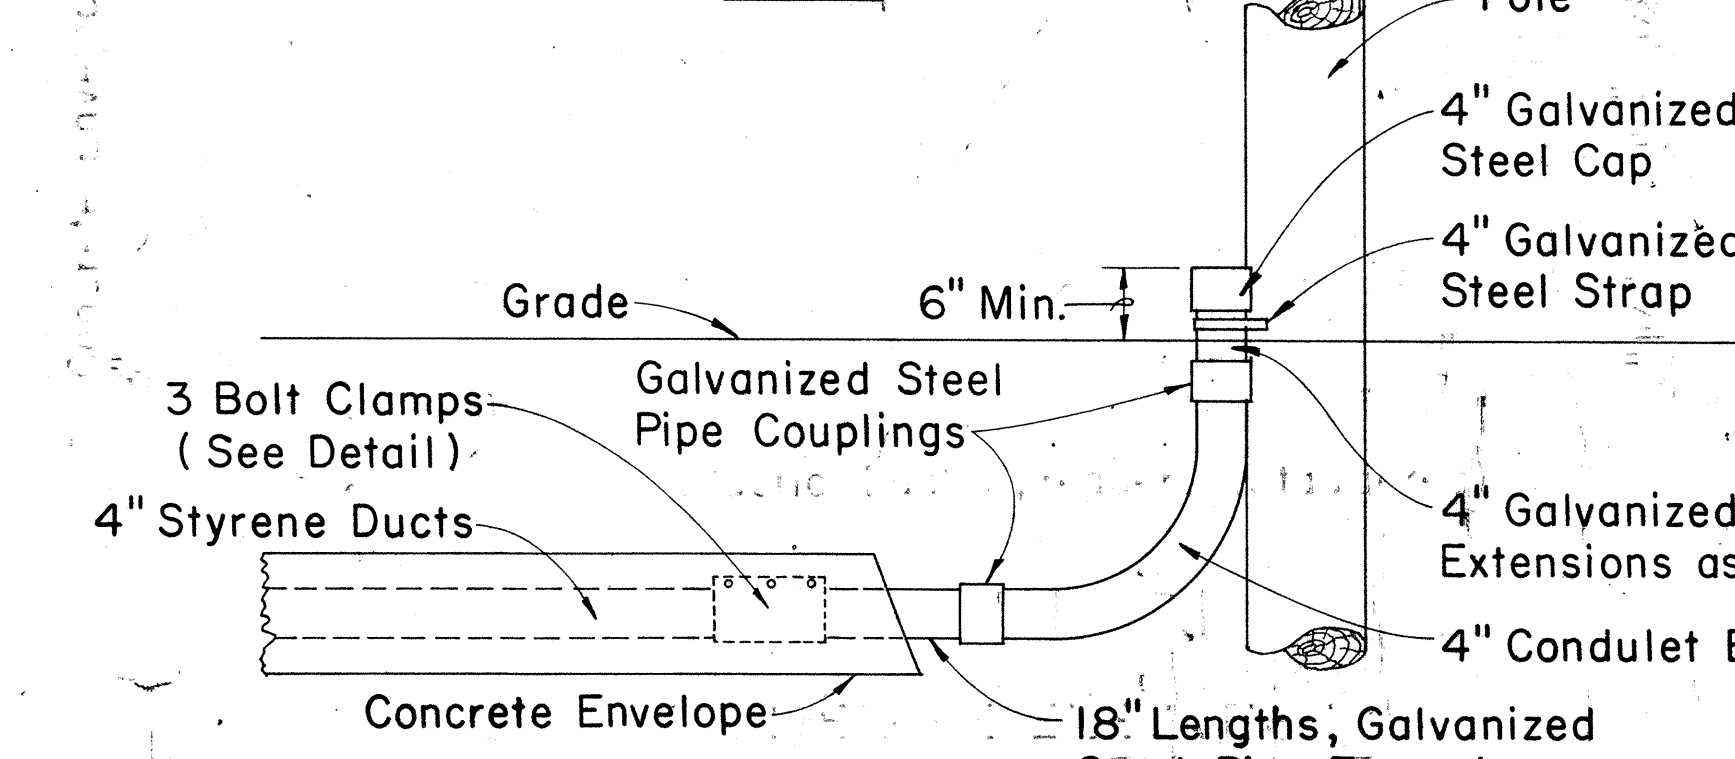

ELEVATION
TYPICAL INSTALLATION DETAILS
Scale: 3/4" = 1'-0"

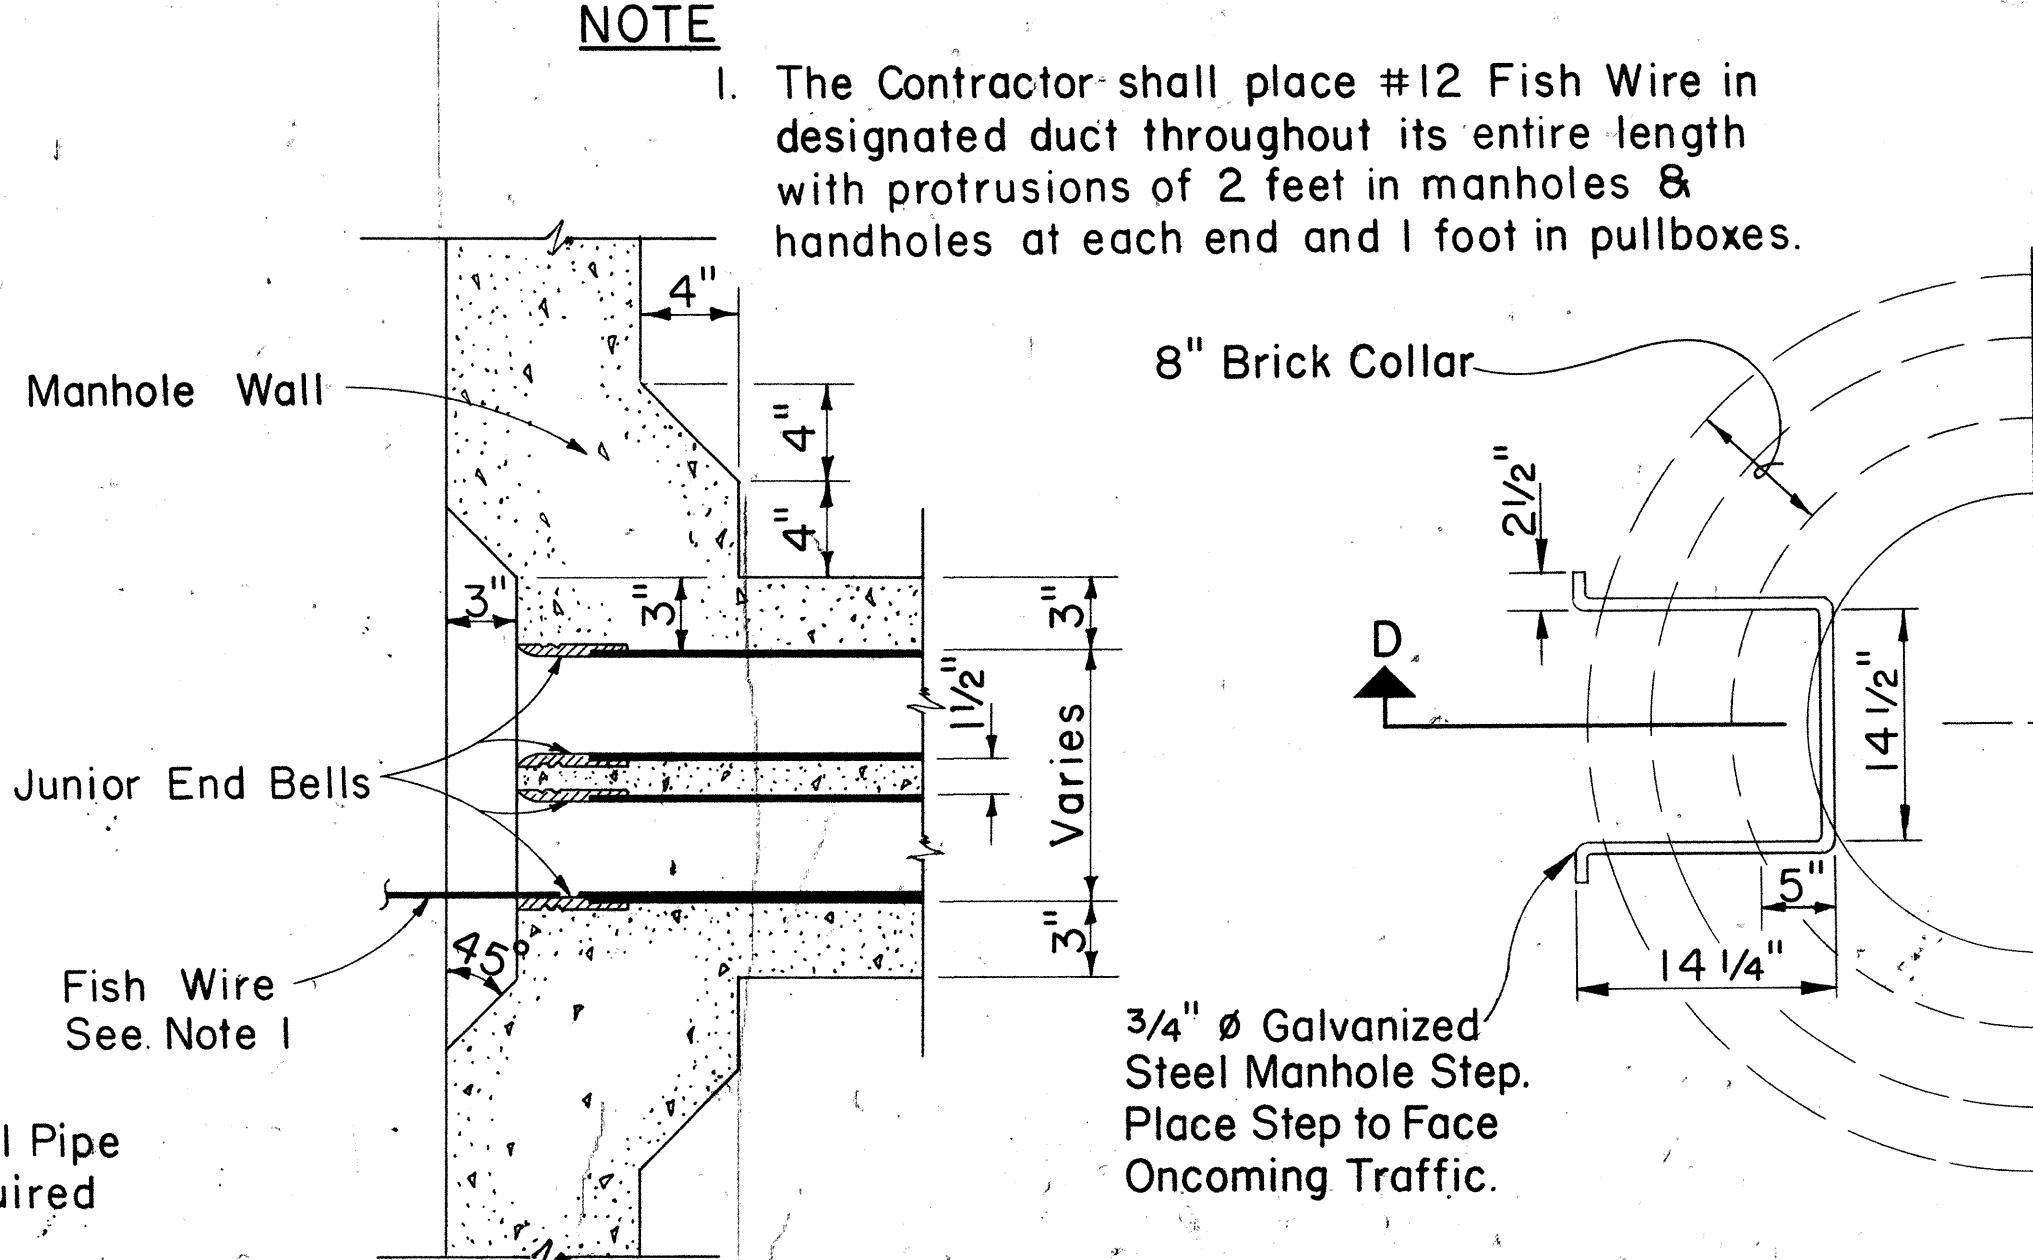

SECTION "F-F"
TYPICAL WINDOW DETAIL & JUNIOR END BELL
Scale: 1 1/2" = 1'-0"

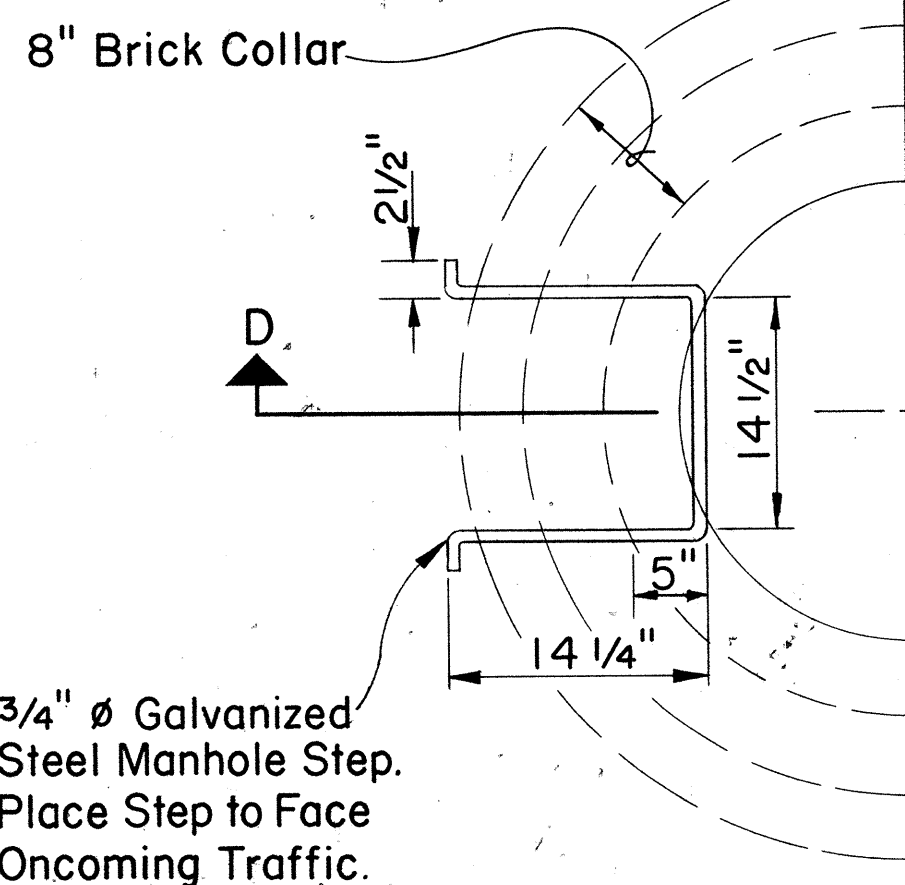

PART-PLAN MANHOLE STEP
Scale: 1" = 1'-0"

NOTE

- The Contractor shall place #12 Fish Wire in designated duct throughout its entire length with protrusions of 2 feet in manholes & handholes at each end and 1 foot in pullboxes.

Supplement Sheet to Type "A-1" (Drawing Nos. 34060 & 34061), Type "A-2" (Drwg. Nos. 34062 & 34063) and Type "A-3" (Drwg. Nos. 34064 & 34065) Telephone M.H.


APPROVED:
[Signature] 2-12-80
Hawaiian Telephone Co., Ltd. Date

STATE OF HAWAII
DEPARTMENT OF TRANSPORTATION
HIGHWAYS DIVISION
STANDARD DETAILS
TYPE "A" MANHOLE
AND MISCELLANEOUS
TELEPHONE DETAILS


Scale: As Noted Date: SEPT. 1979
SHEET No. 8 OF 8 SHEETS

NOTES:

1. FOR GENERAL NOTES AND MISCELLANEOUS DETAILS, REFER TO DWG. 16688 (2 SHEETS).
2. MAXIMUM CLEARANCES BETWEEN REMOVABLE CONCRETE COVERS AND CONCRETE OPENING AT THE SUPPORTS MUST BE KEPT. CONCRETE CONTRACTOR SHALL MEASURE COVER SLAB STEEL FRAME AFTER FABRICATION TO OBTAIN PROPER CLEARANCES. ANY VARIATION IN CLEARANCES SHALL BE CORRECTED TO THE SATISFACTION OF THE ENGINEER AT CONTRACTOR'S EXPENSE.
3. TWO - 2" Ø G.I. COND. FOR STREET LIGHTING TO BE INSTALLED ONLY WHEN OUTSIDE FACE OF HANDHOLE IS LESS THAN 3" FROM CURBING.
4. TOP OF HANDHOLE SHALL MATCH NEW AND/OR EXISTING GRADES UNLESS OTHERWISE SHOWN OR NOTED ON PLANS OF PROJECT CONCERNED.
5. FOR DUCT ENTRANCES, DEPTH AND LOCATIONS OF PULLING IRONS, SEE HANDHOLE DEVELOPMENTS OF PROJECT CONCERNED.
6. SEE PROJECT DRAWING FOR LOCATION OF HANDHOLE CONCERNED.

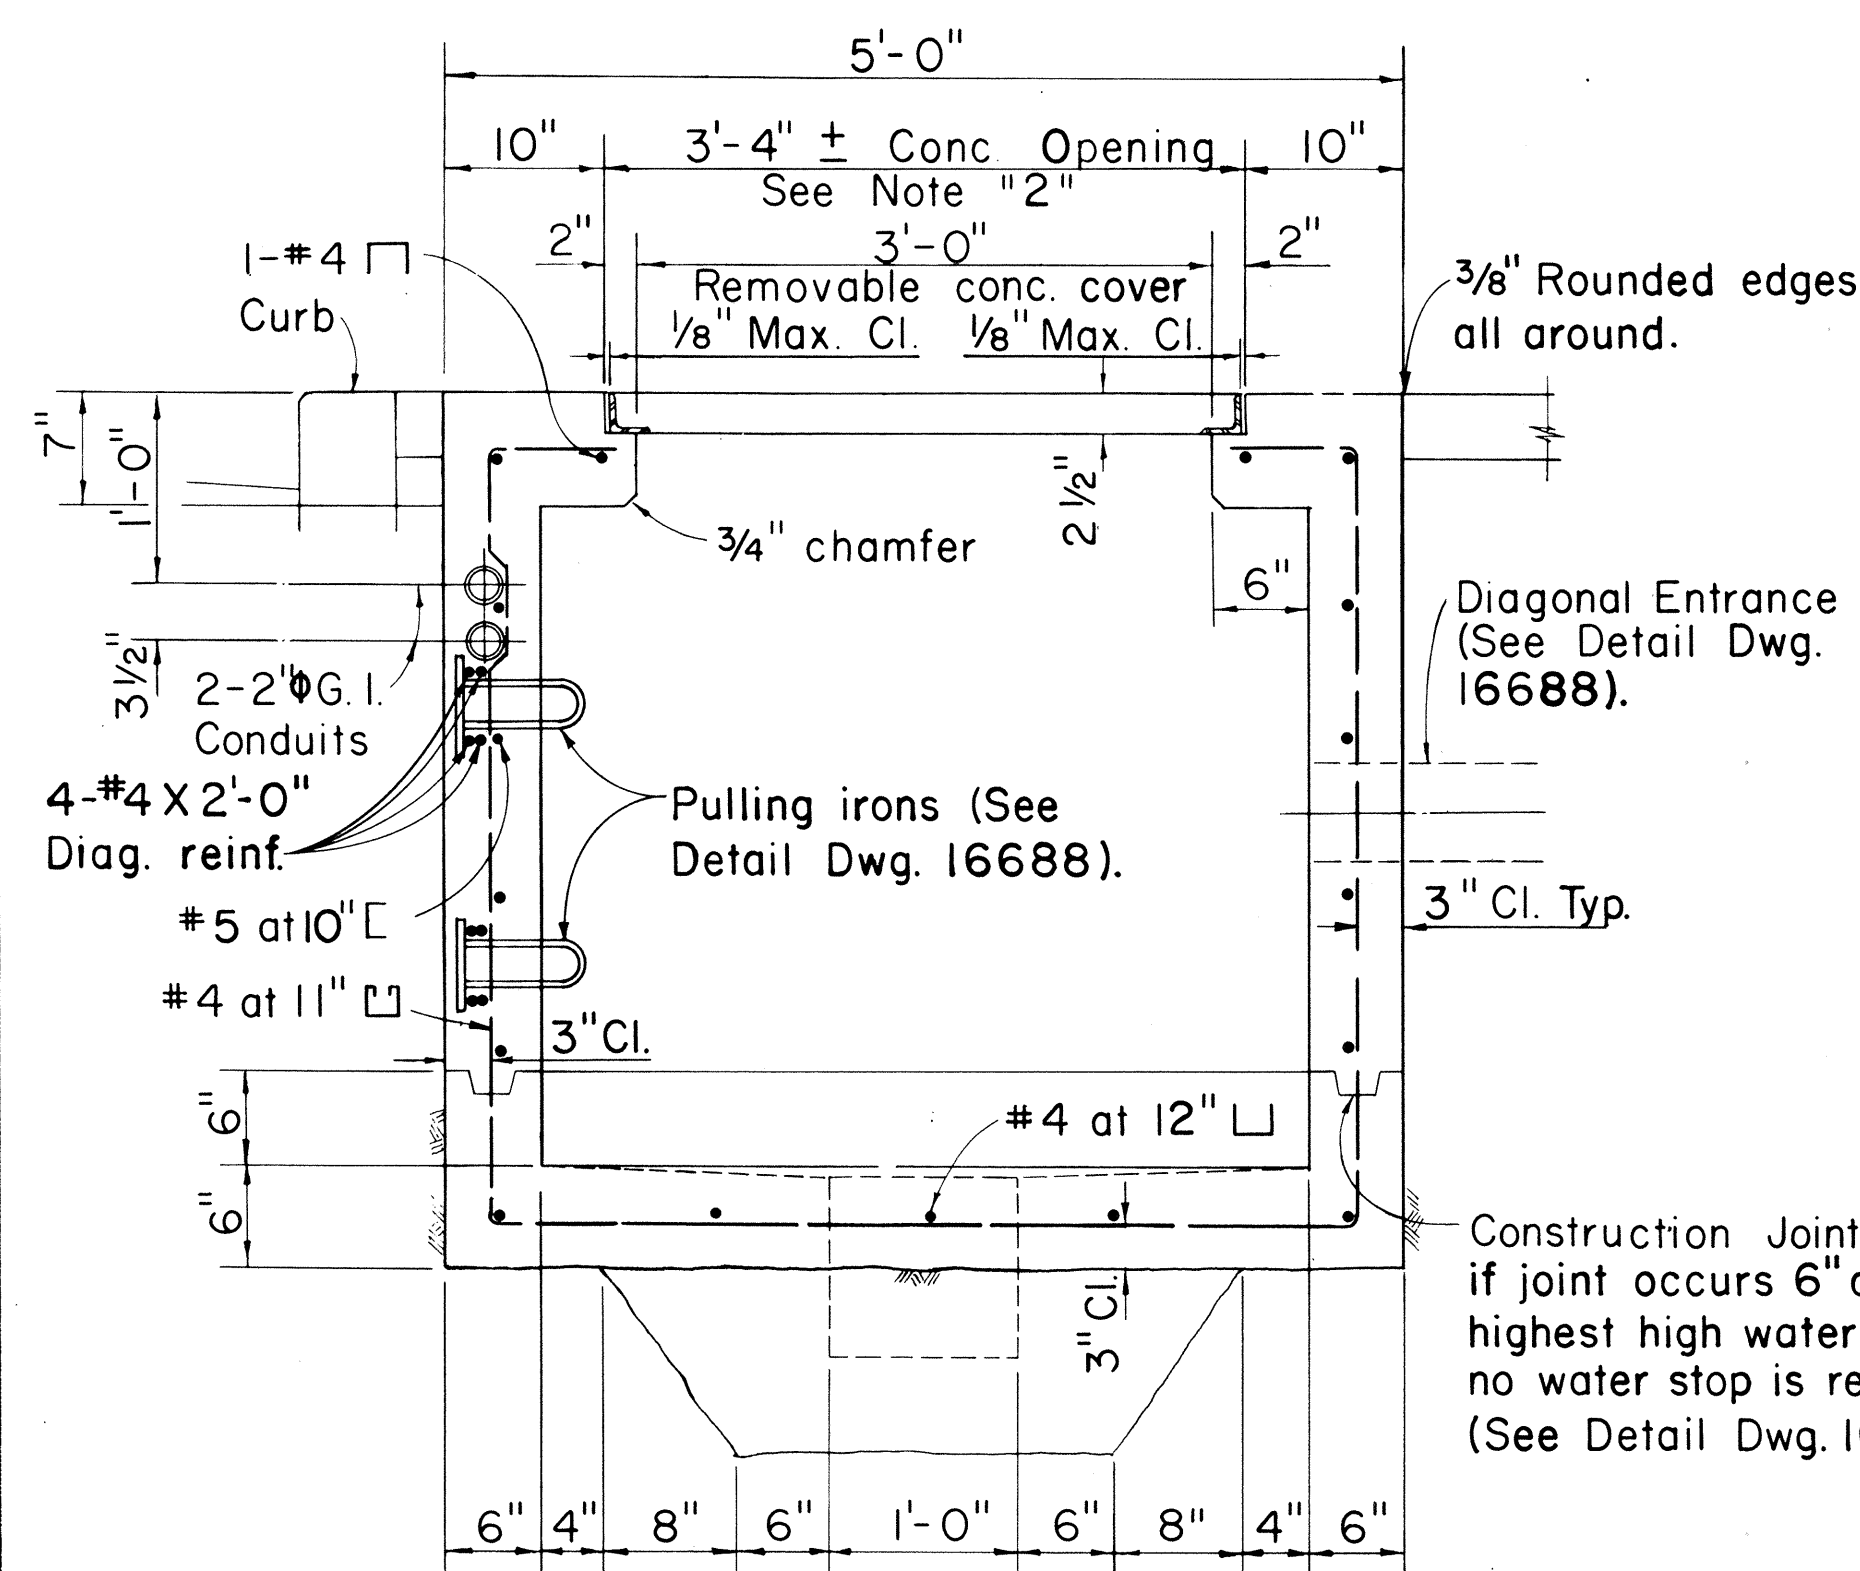


SECTION "B-B"
Scale: 1" = 1'-0"

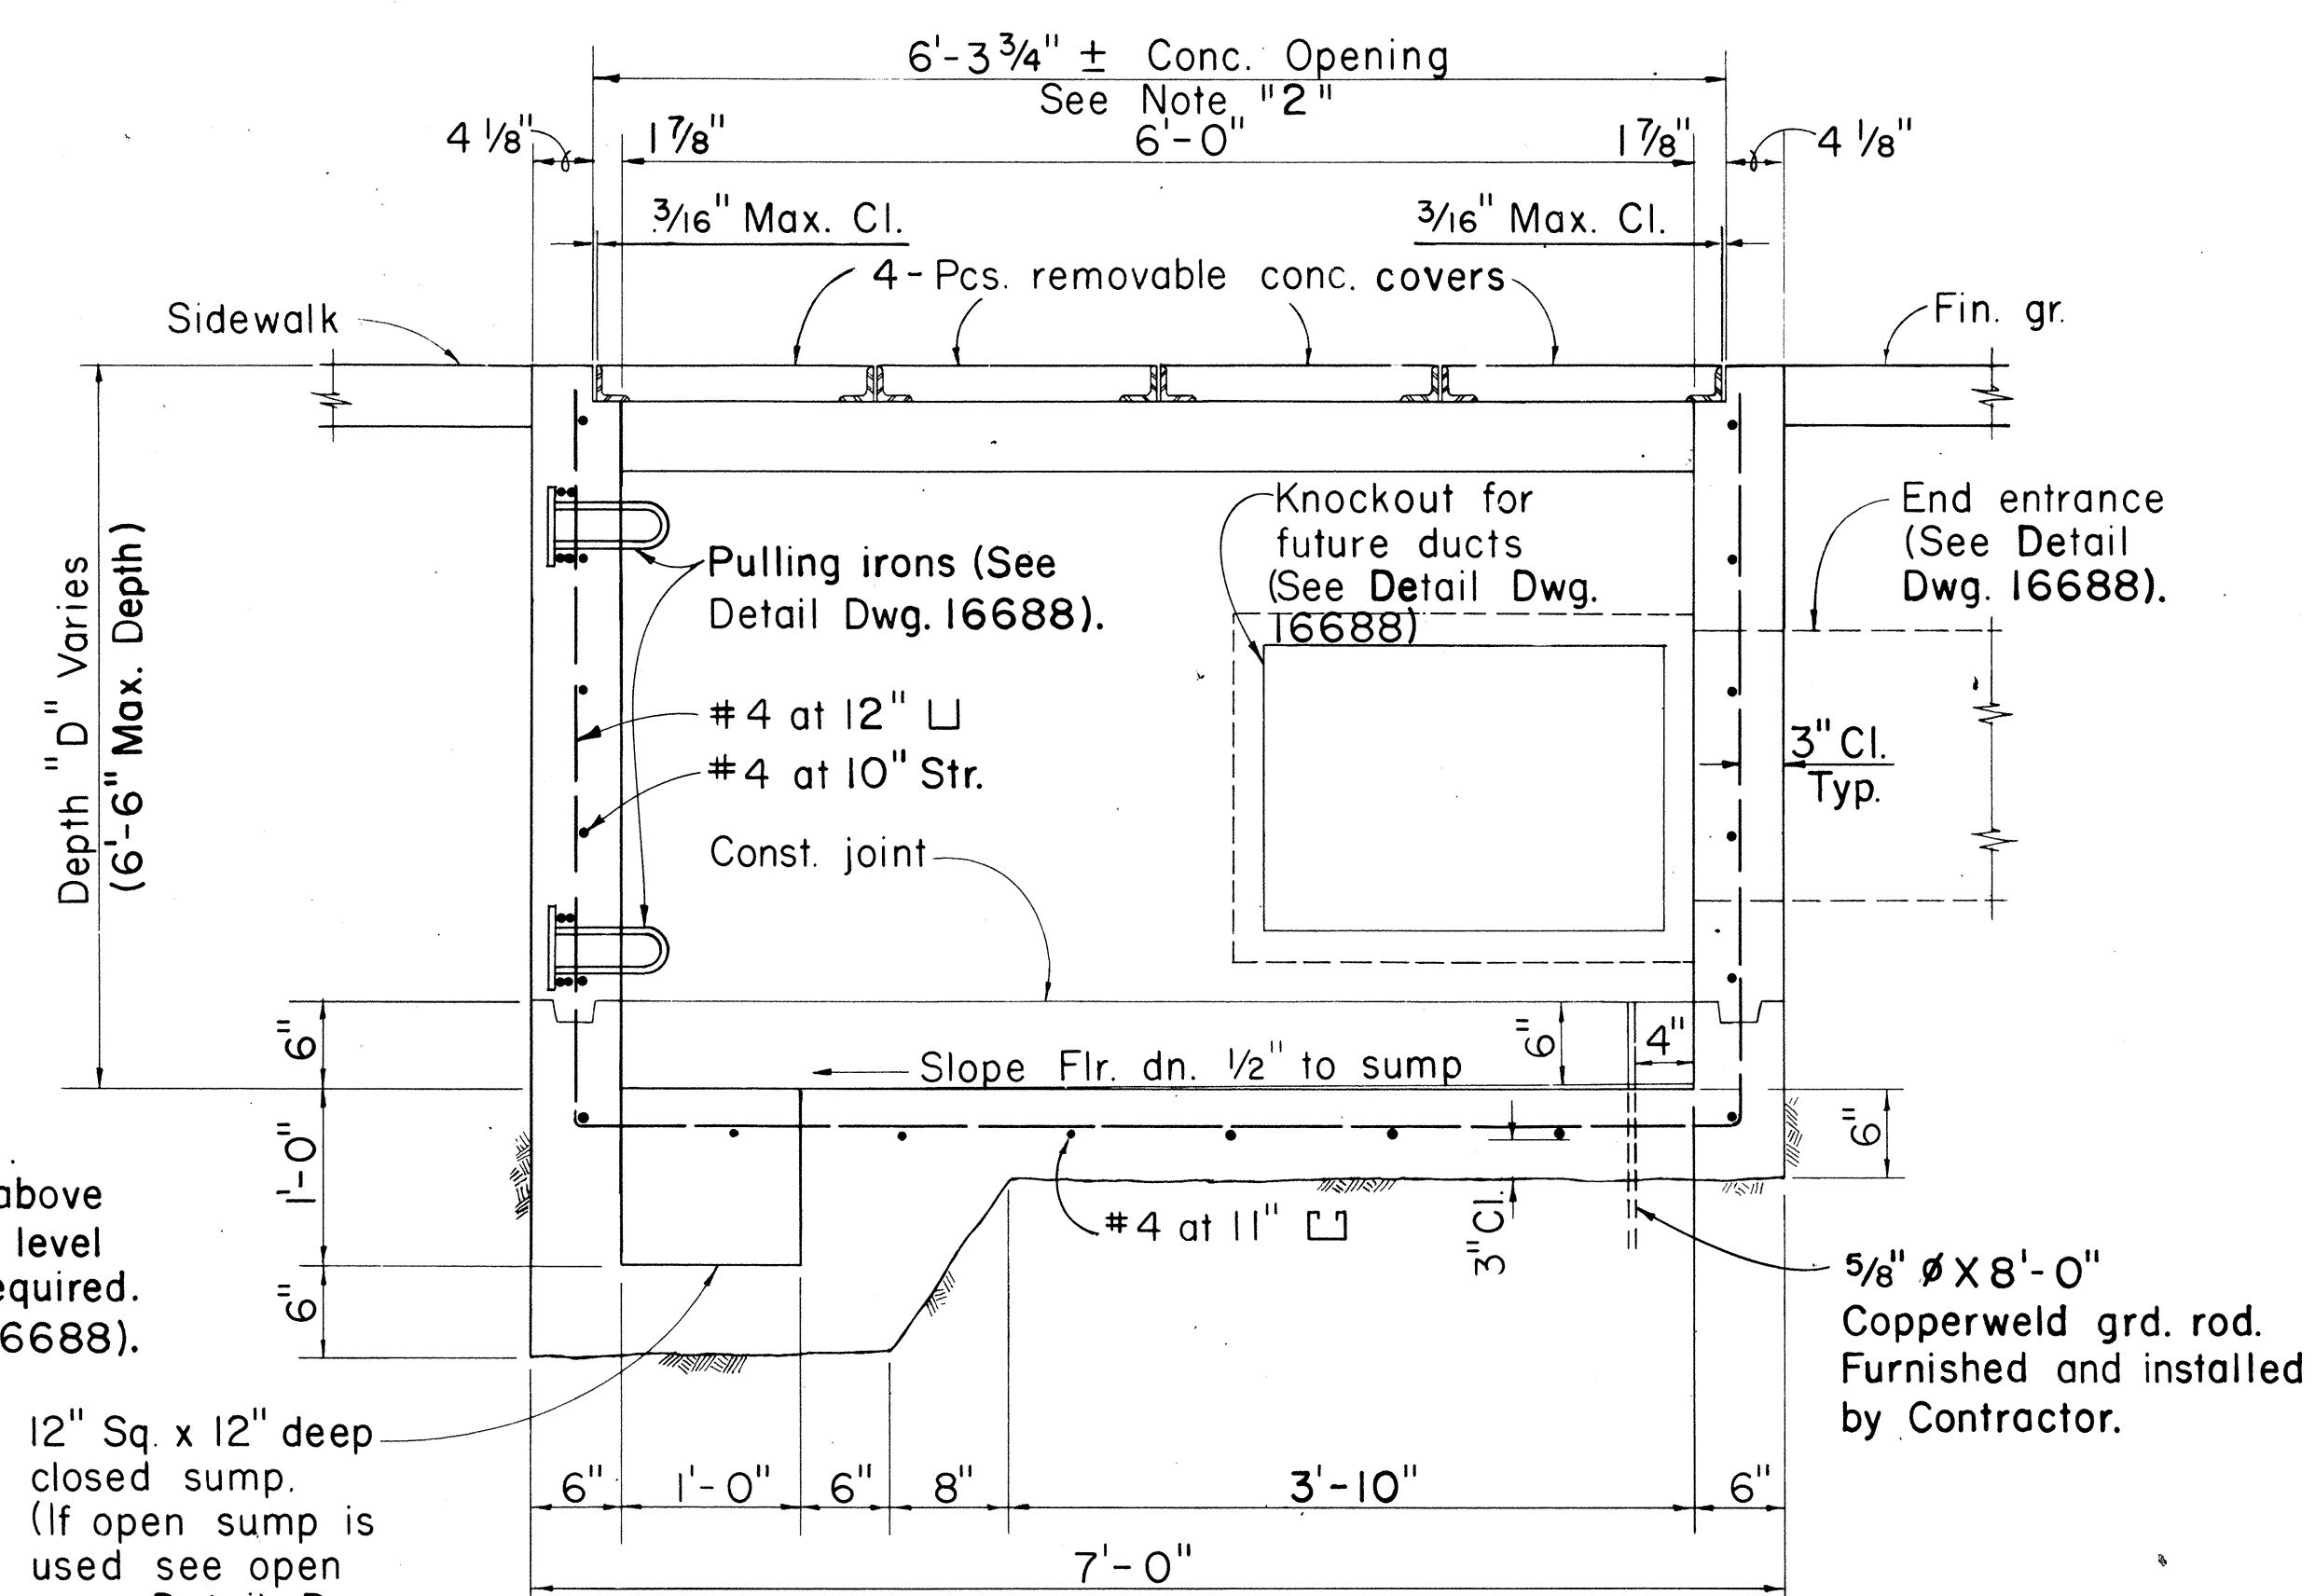

SECTION "A-A"

Scale: 1"=1'-0"

12" Sq. x 12" deep —
closed sump.
(If open sump is
used see open
sump Detail. Dwg.
16688 - No reinf. thru
sump).

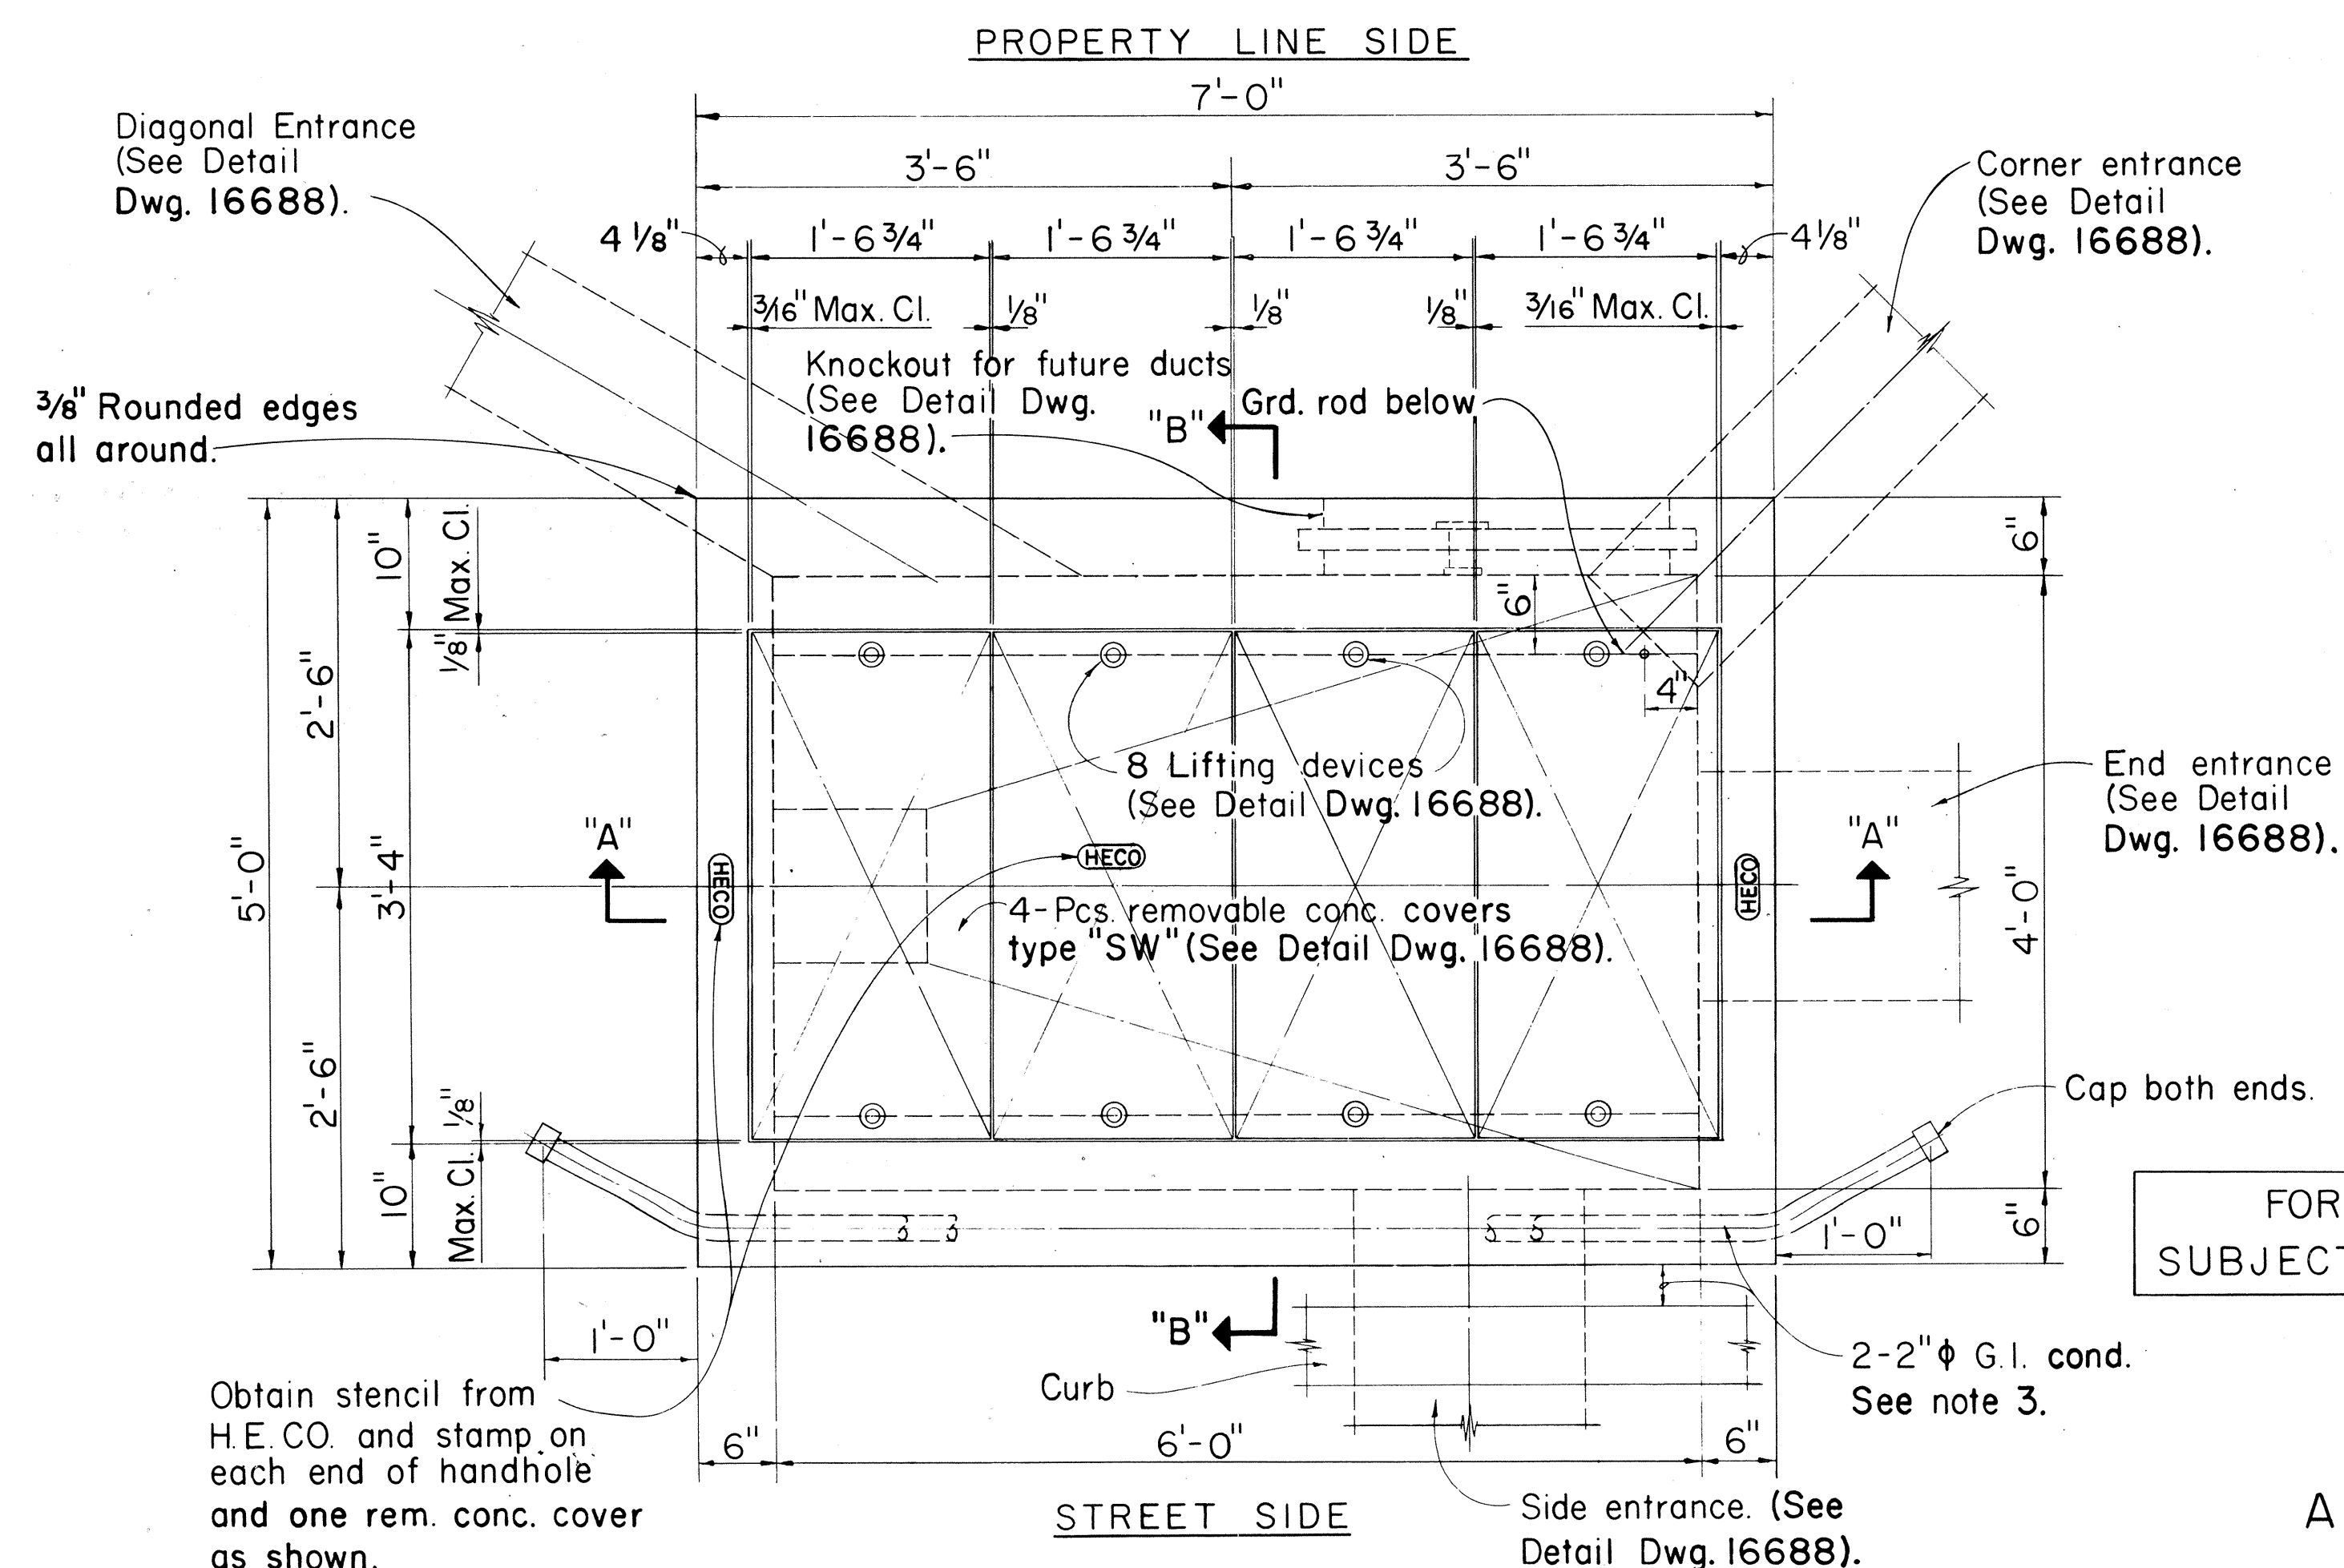

STREET SIDE
TOP PLAN
Scale: 1" = 1' - 0"

FOR USE IN AREAS NOT
SUBJECT TO VEHICULAR TRAFFIC

APPROVED:

109 W. K. C. S. S.
HAWAIIAN ELECTRIC CO., INC.

2-22-80
DATE









DD - 630.015 SHEET No. 1 OF 6 SHEETS

HECo., Inc.	Drawing	Number
18842	SHEET No. 1 OF 1 SHEET	
STATE OF HAWAII DEPARTMENT OF TRANSPORTATION HIGHWAYS DIVISION		
<u>STANDARD DETAILS</u>		
<u>HANDHOLE TYPE</u>		
<u>46 (4'-0" x 6'-0")</u>		
<u>UNDERGROUND STANDARDS</u>		
Scale: As Shown		




ORIGINAL PLAN	SURVEY PLOTTED BY _____ DATE _____	
	DRAWN BY _____	46
NOTE BOOK	TRACED BY _____	46
	DESIGNED BY _____	46
	QUANTITIES BY _____	46
	CHECKED BY _____	46
No. _____	PAGE NO. _____	

GENERAL NOTES FOR MANHOLES
& HANDHOLES STANDARD DETAILS

1. All work shall be subject to inspection by the Hawaiian Electric Co., Inc., Contracting & Inspection Division, City & County of Honolulu and/or Land Transportation Facilities Division, State of Hawaii, whichever Government has authority over the work.
2. Contractor shall notify the Hawaiian Electric Co., Inc., Contracting & Inspection Division, phone 546-4427 or 548-4428 24 hours before proceeding with any work on facilities owned by Hawaiian Electric Co., Inc..
3. Ducts: For number, size and exact location of Duct Entrances, refer to Project Drawings.
4. Pulling Irons: For number and locations, refer to Project Drawings.

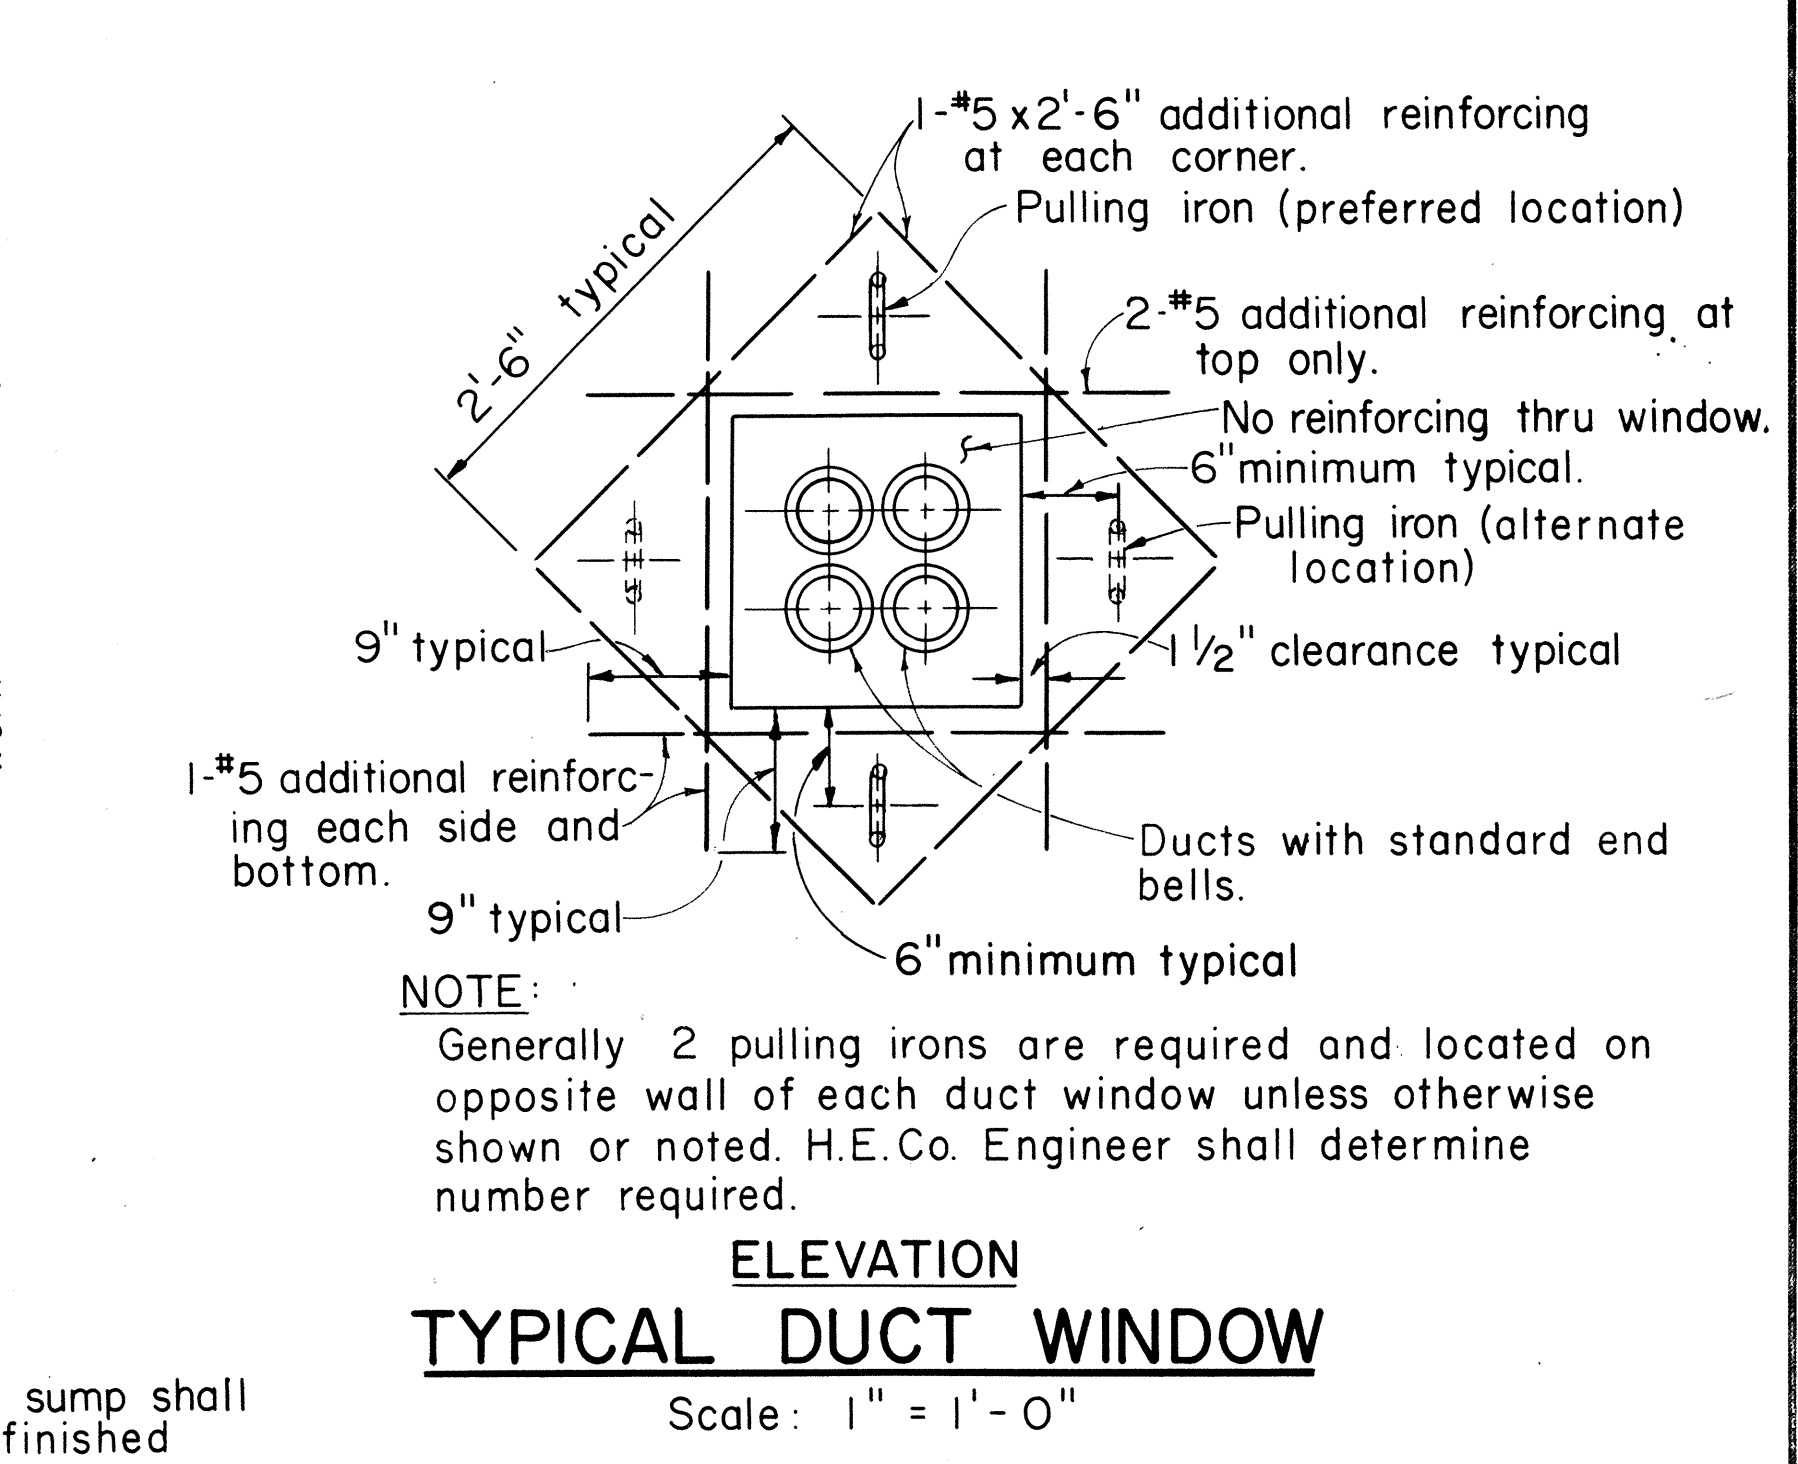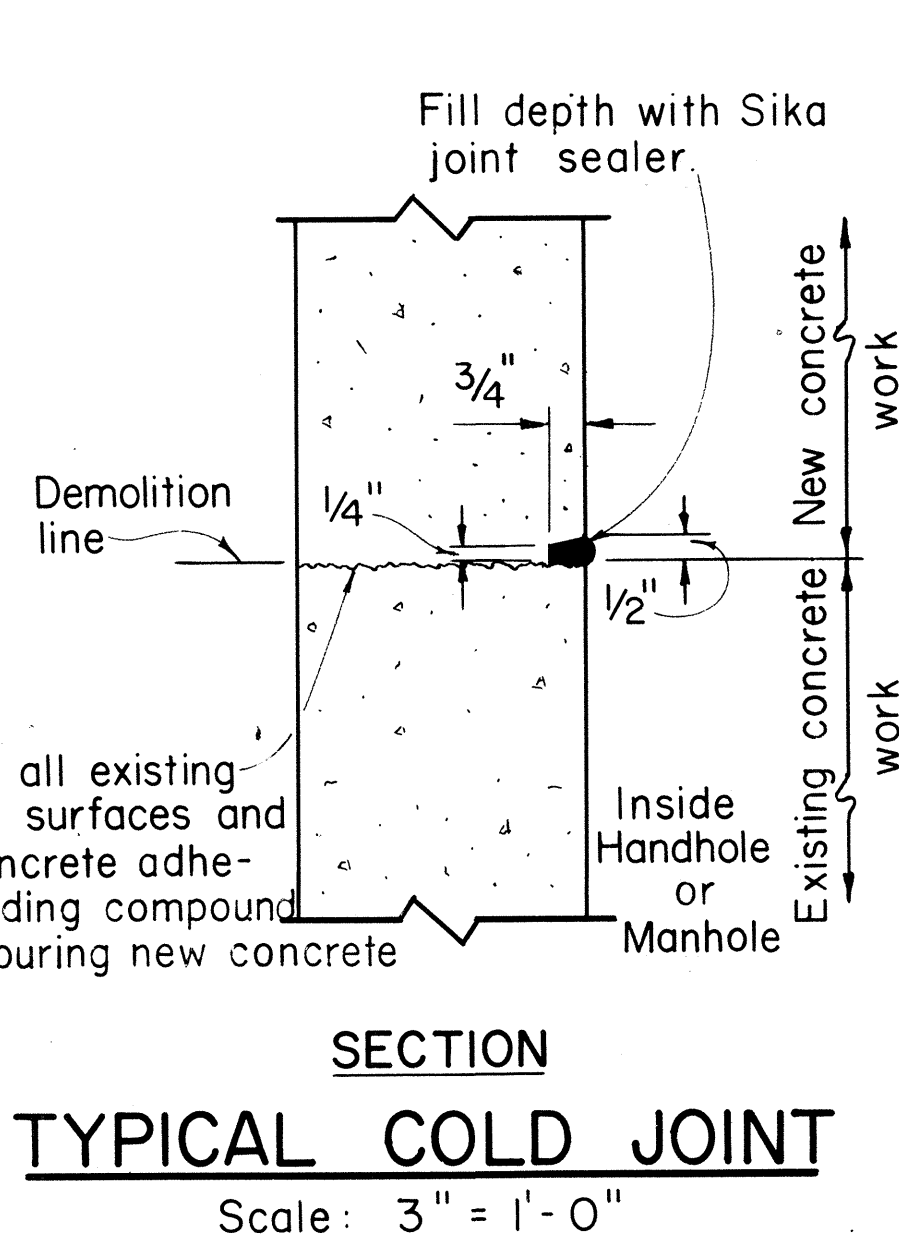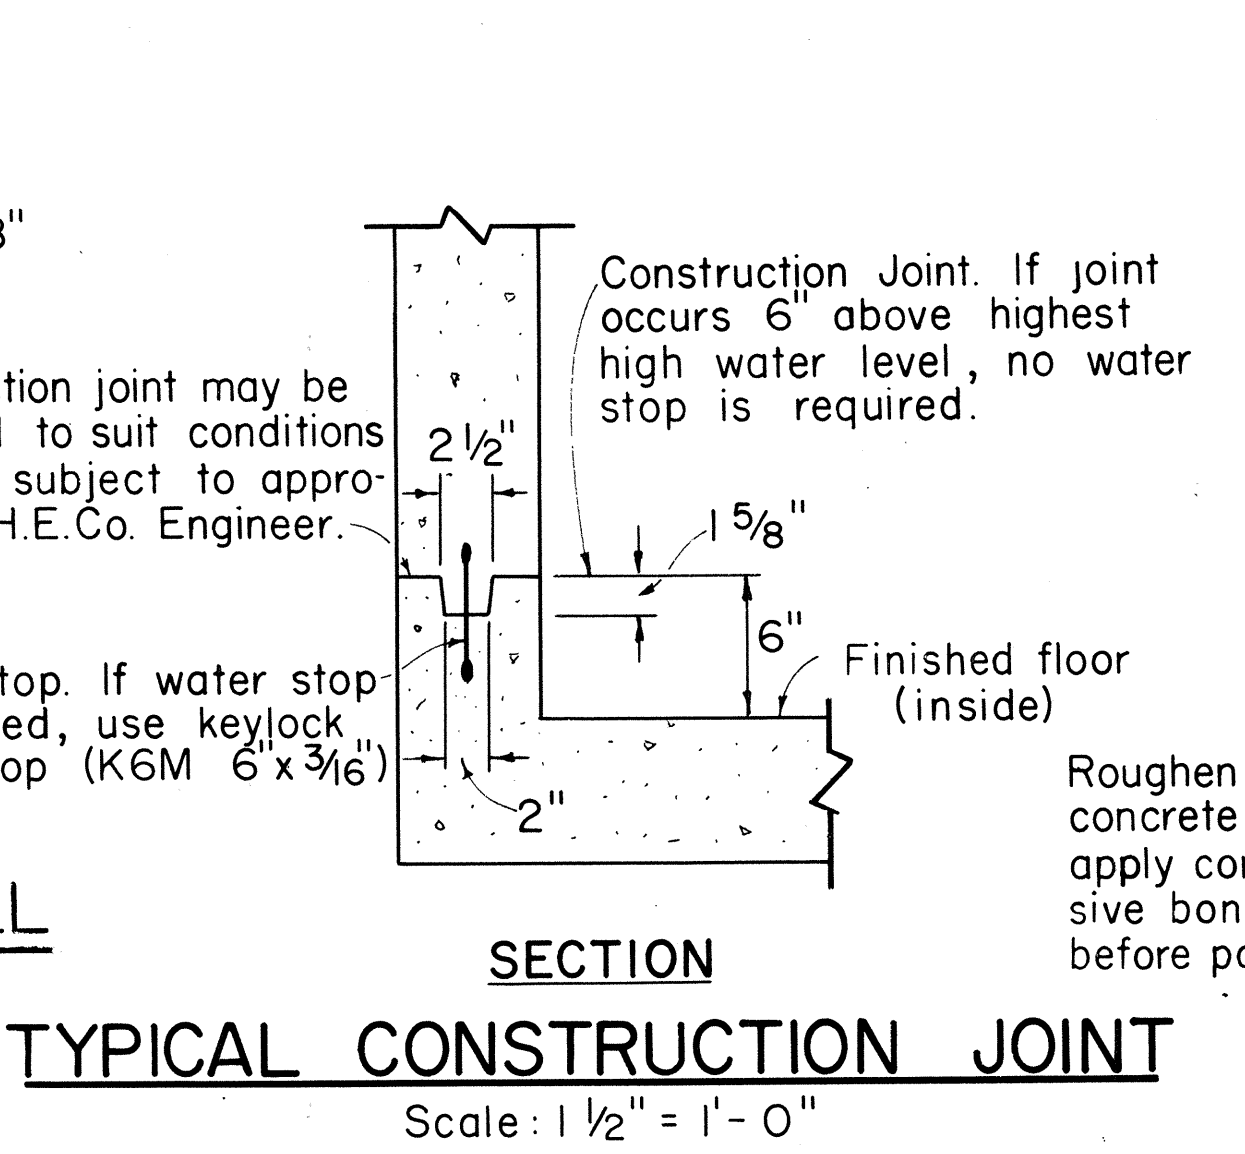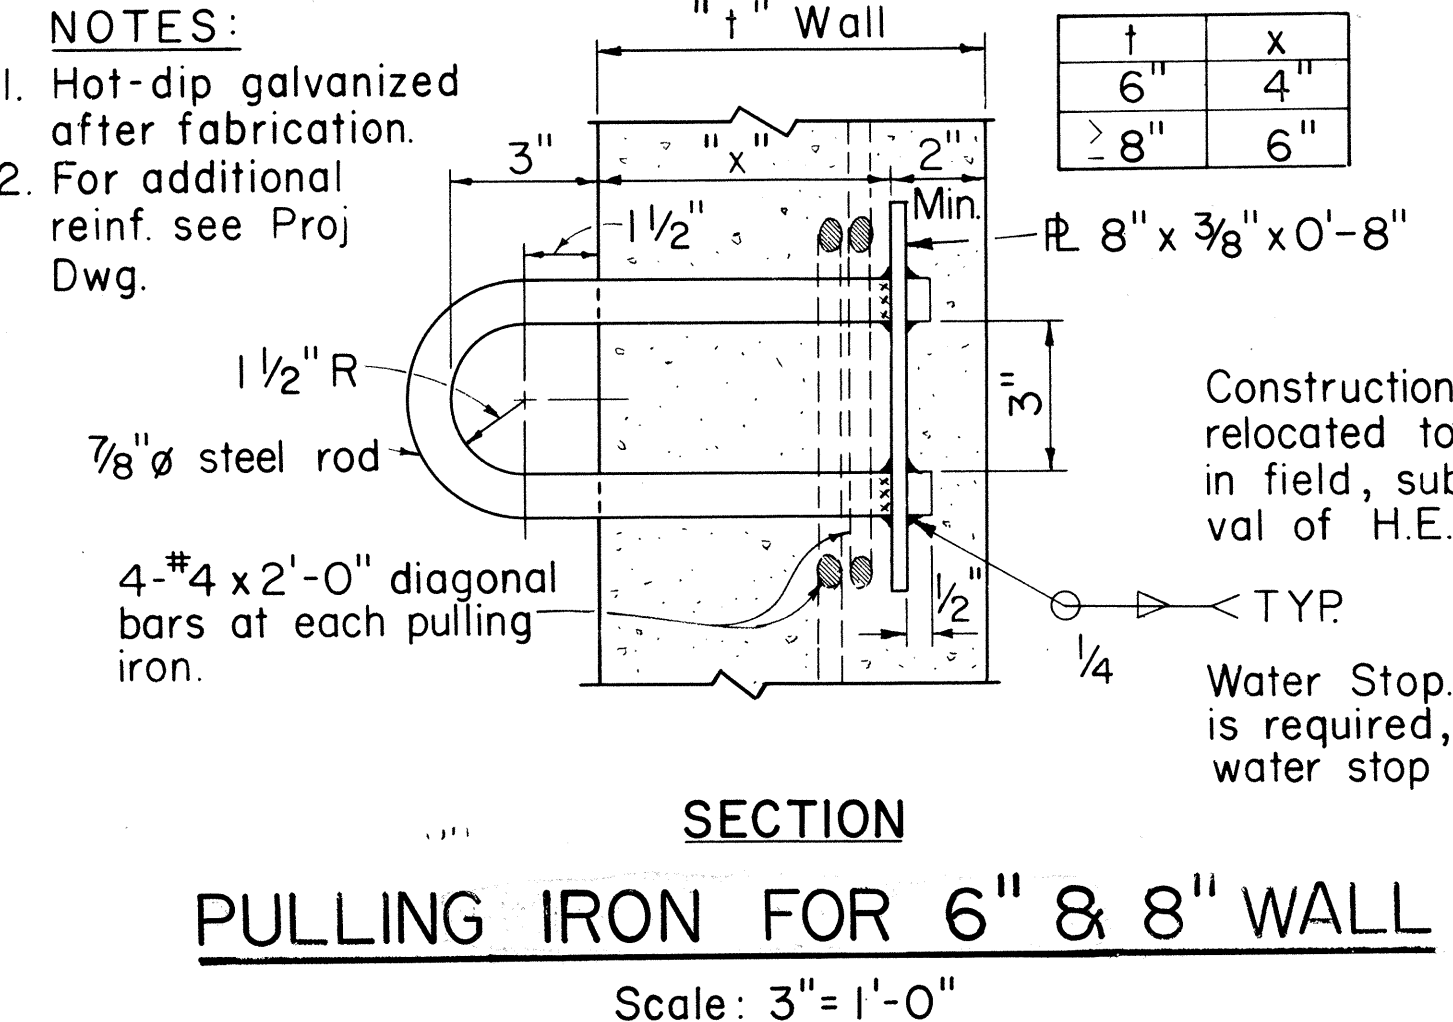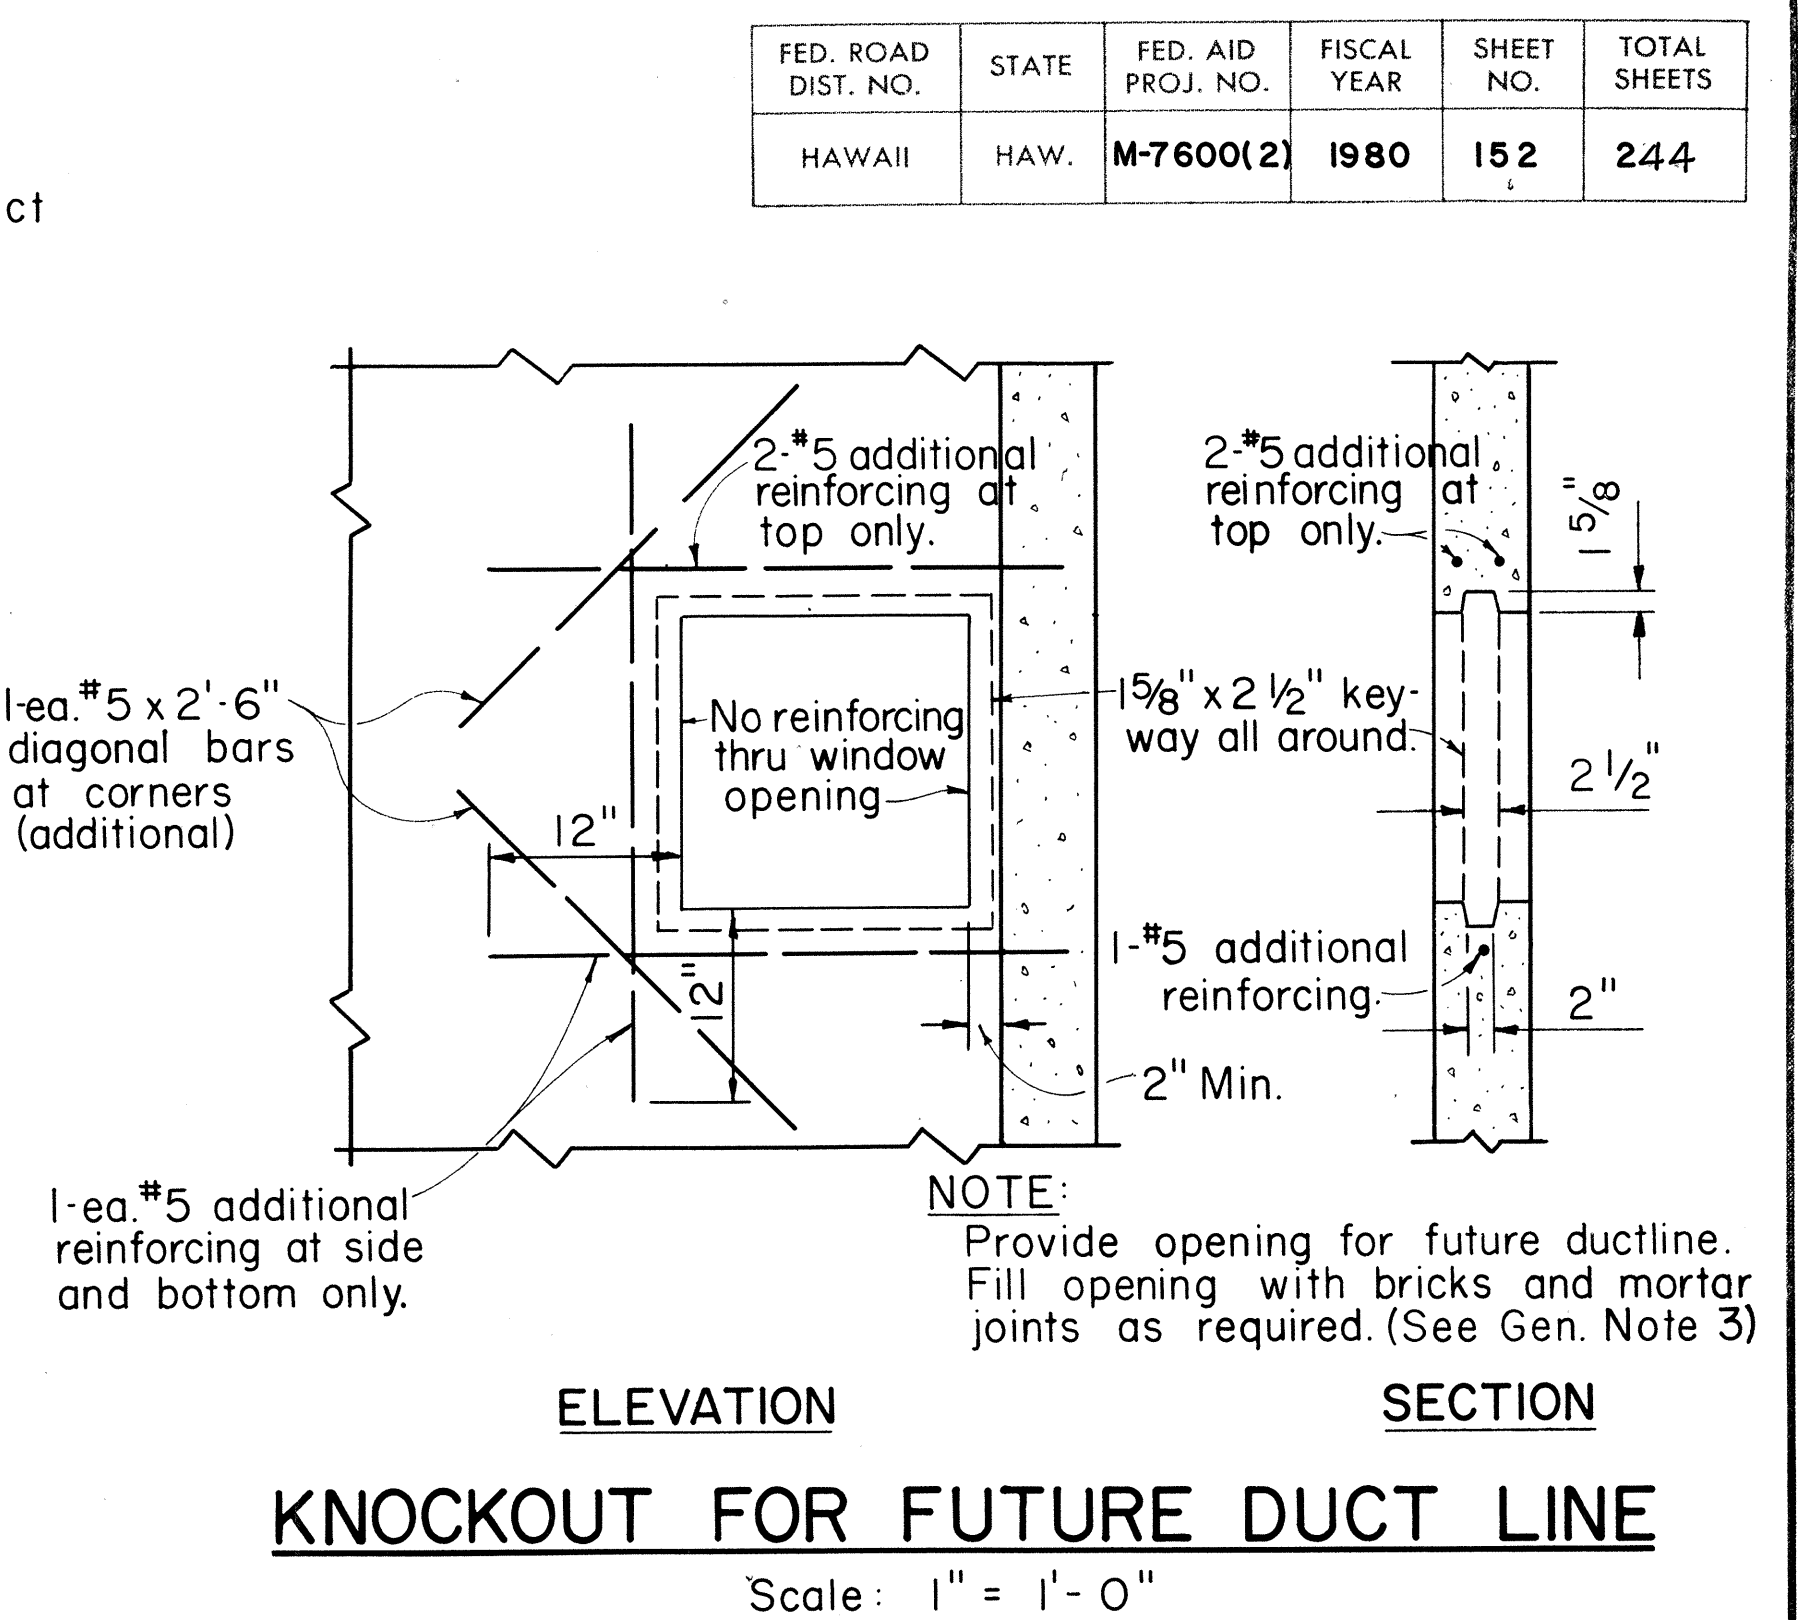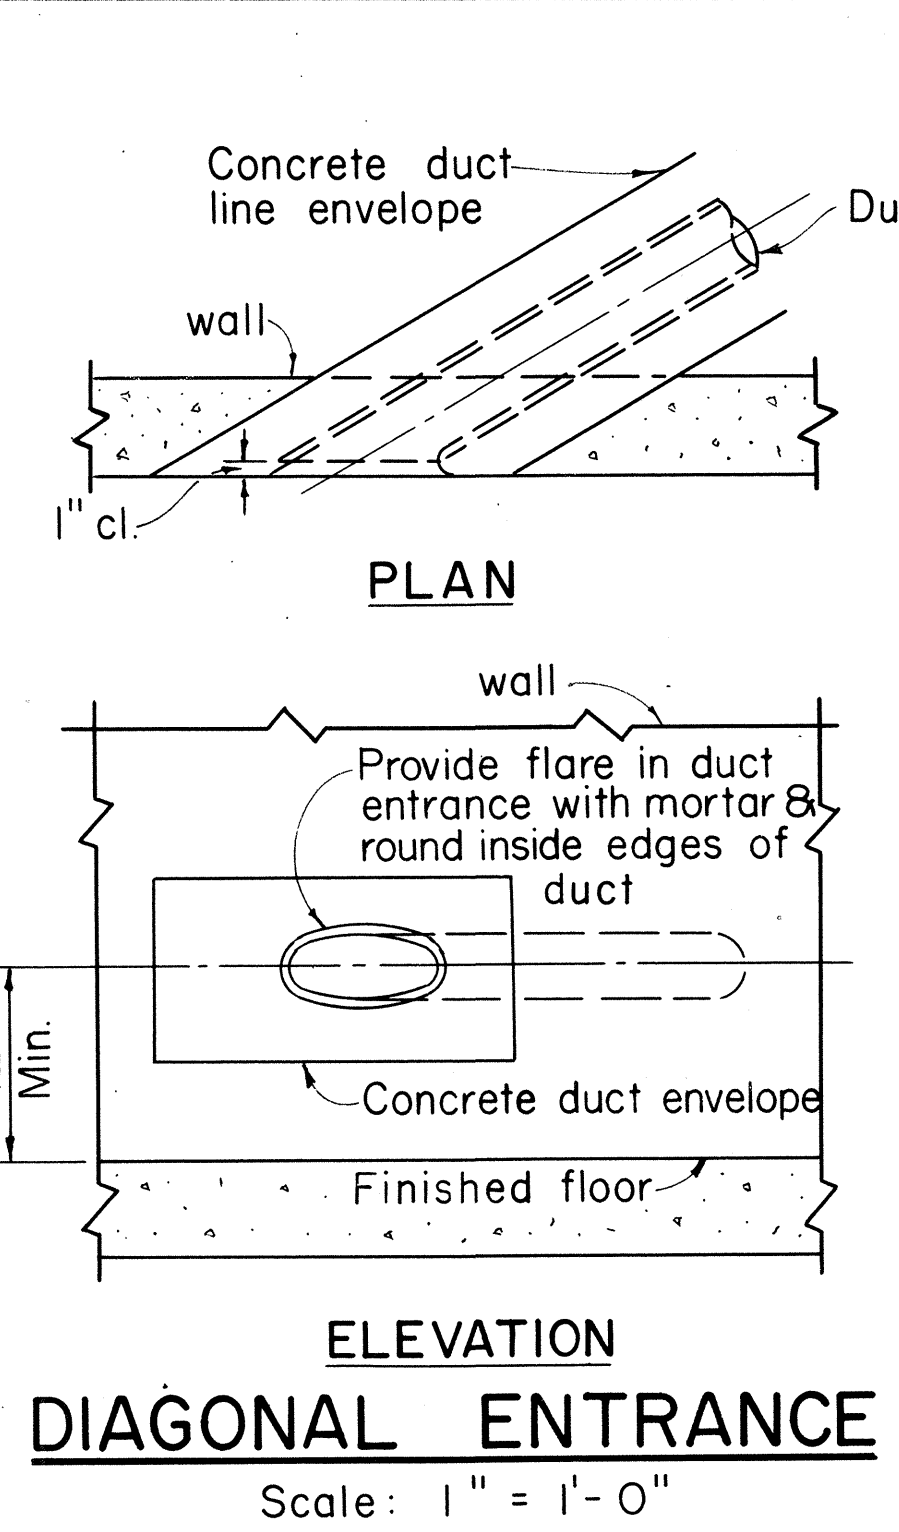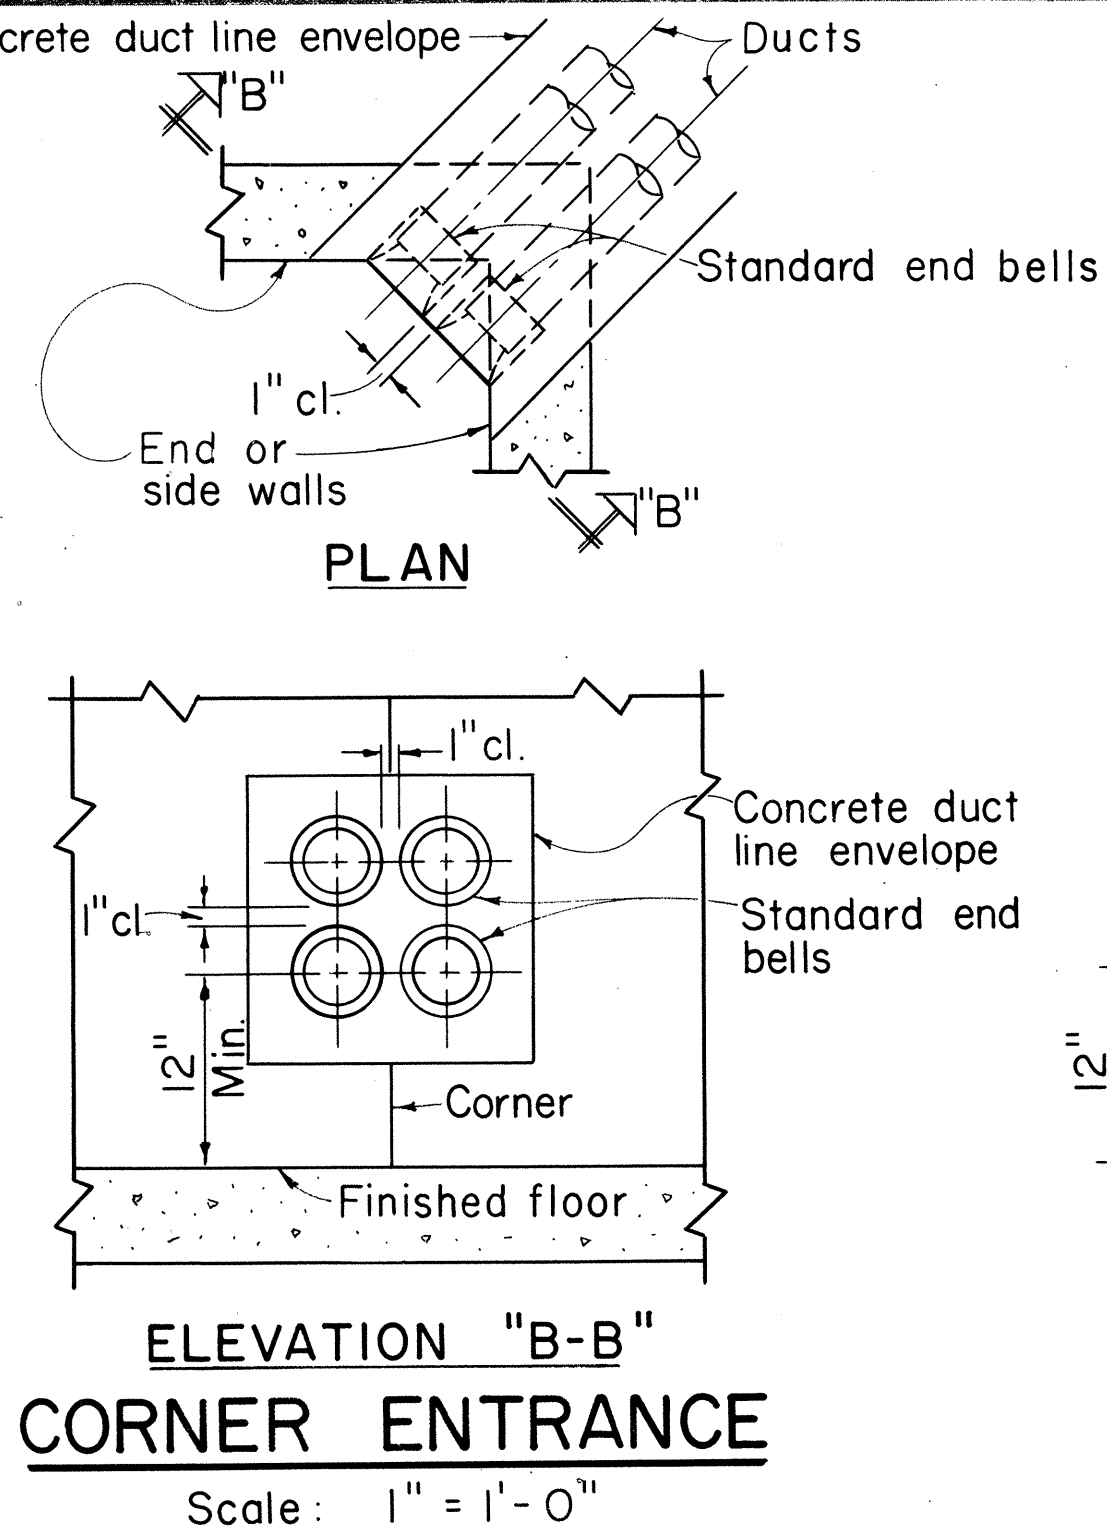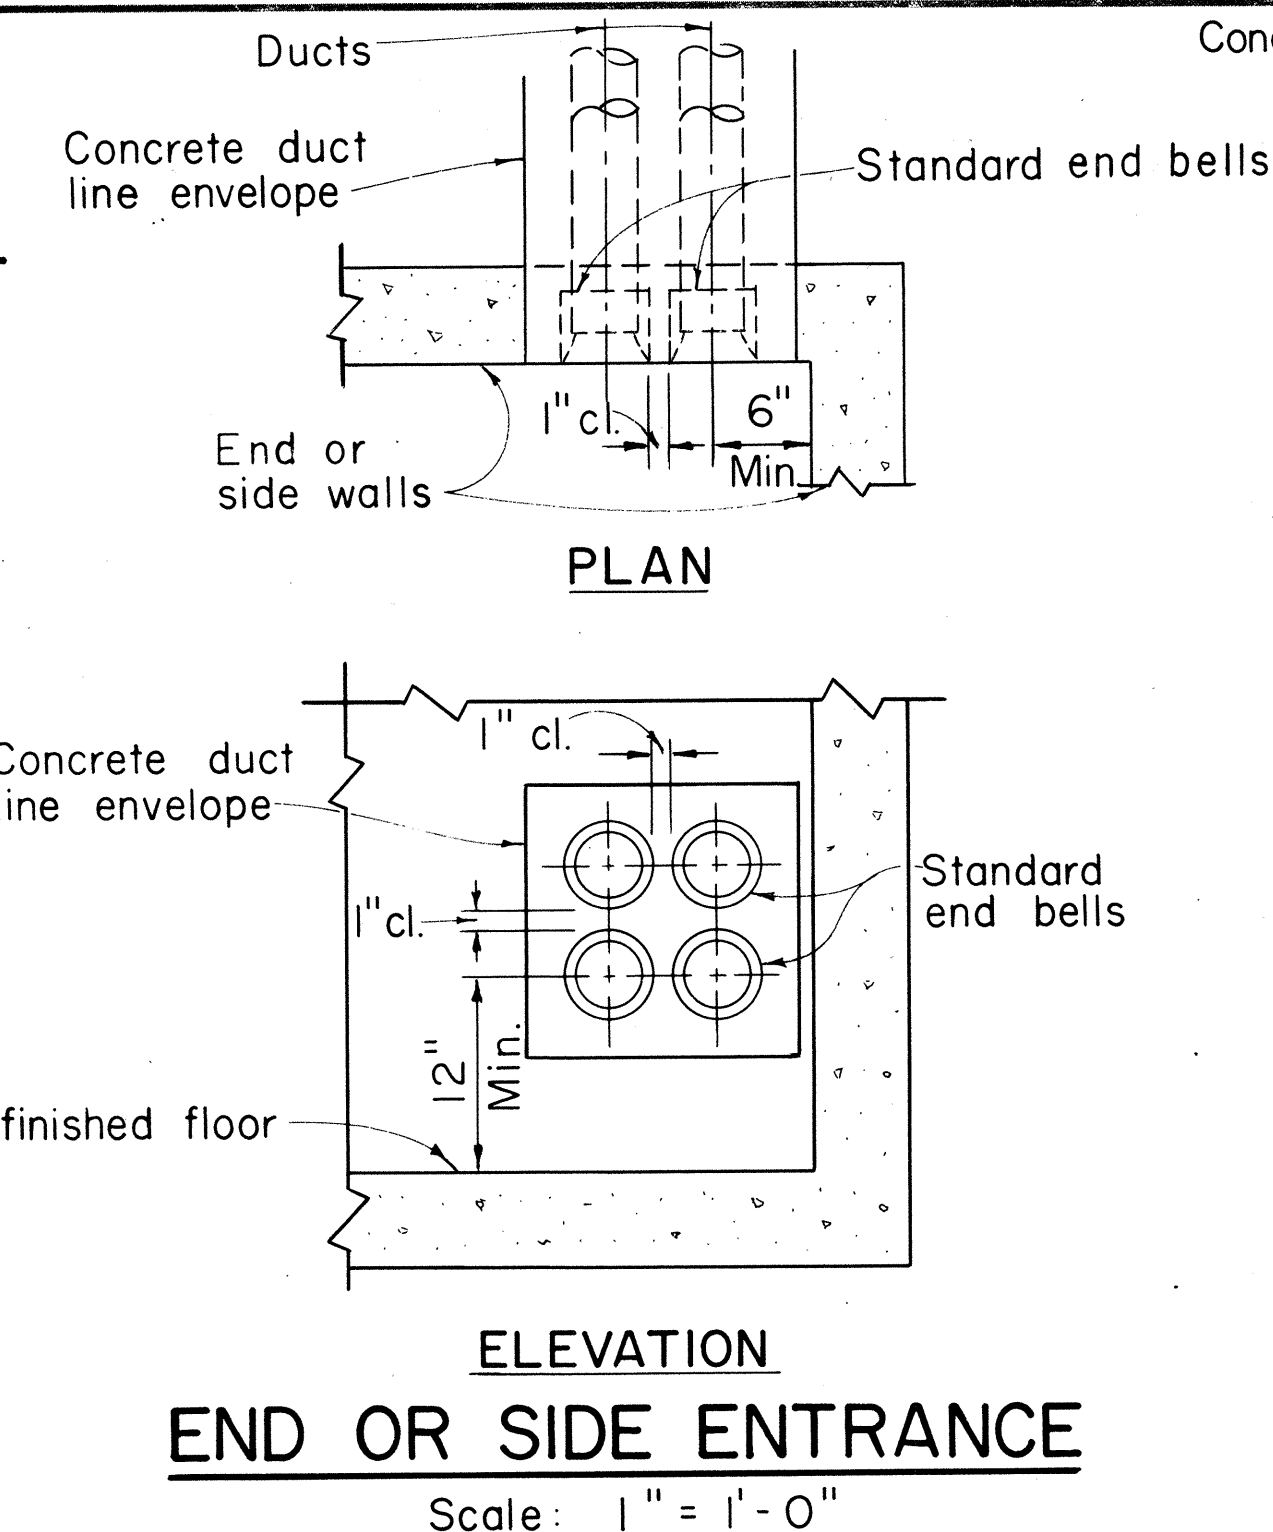

DATE	DESIGNED BY	CHECKED BY
PLAN	DESIGNED BY	CHECKED BY
NOTE BOOK	DESIGNED BY	CHECKED BY
No.	DESIGNED BY	CHECKED BY

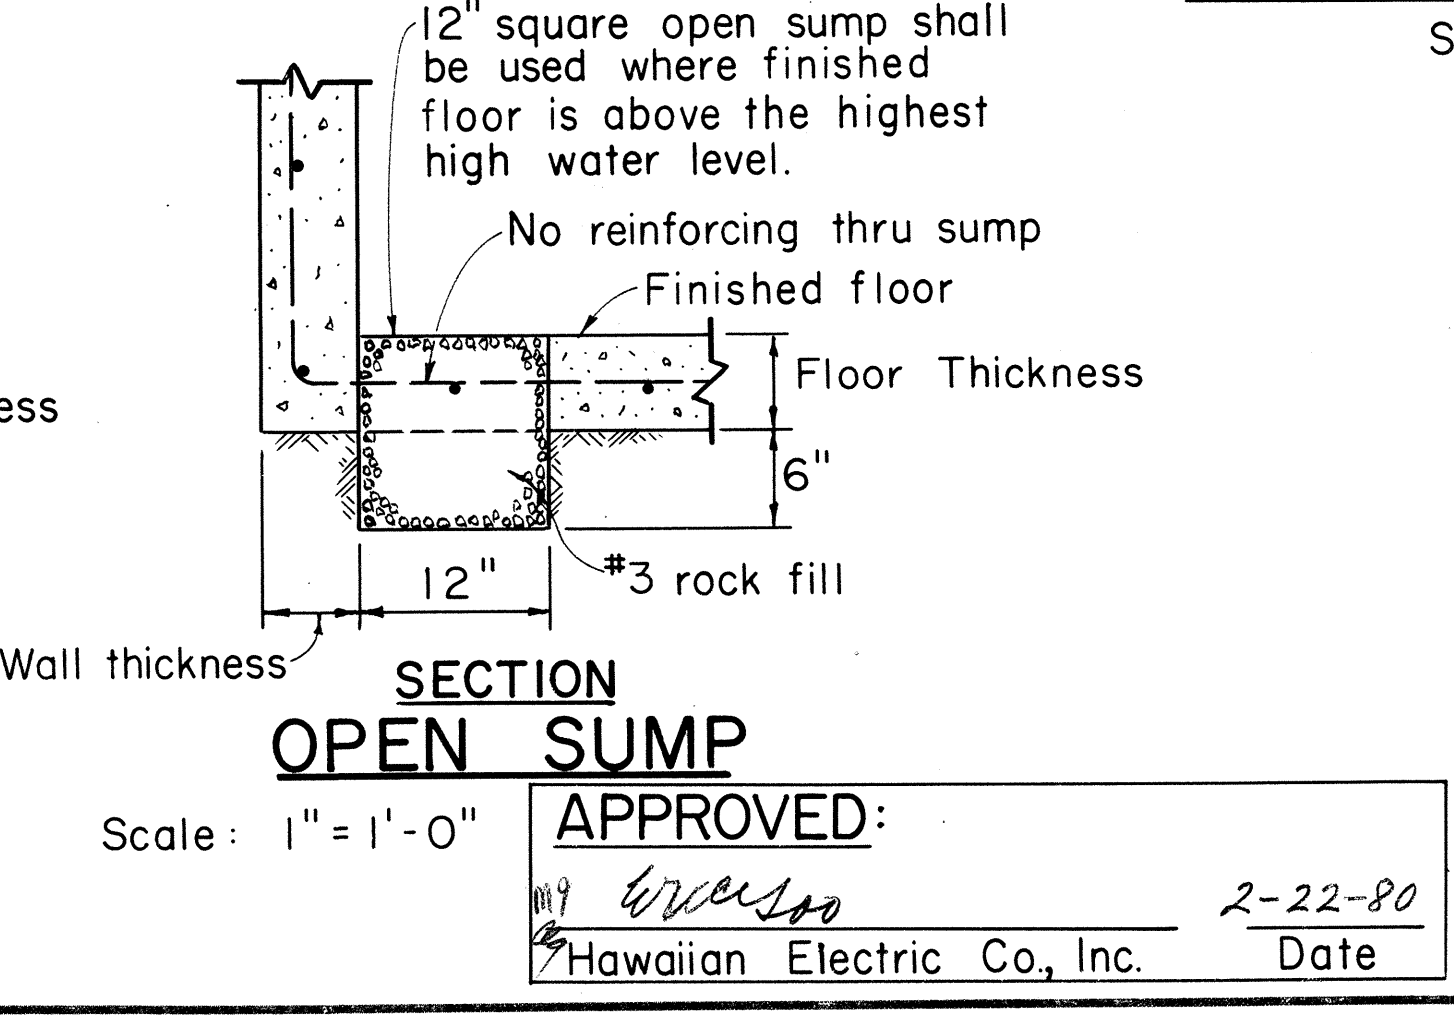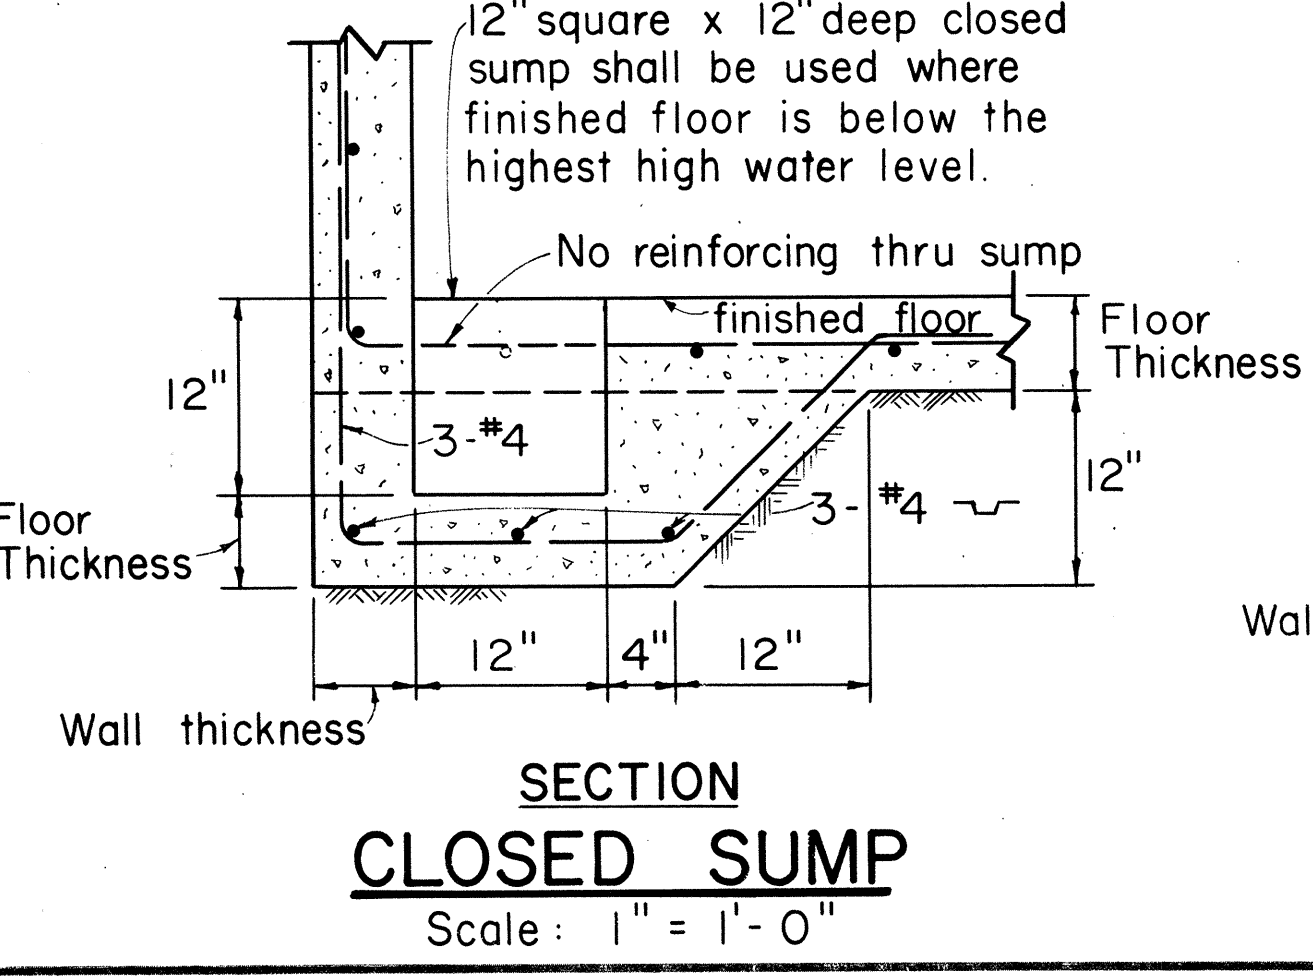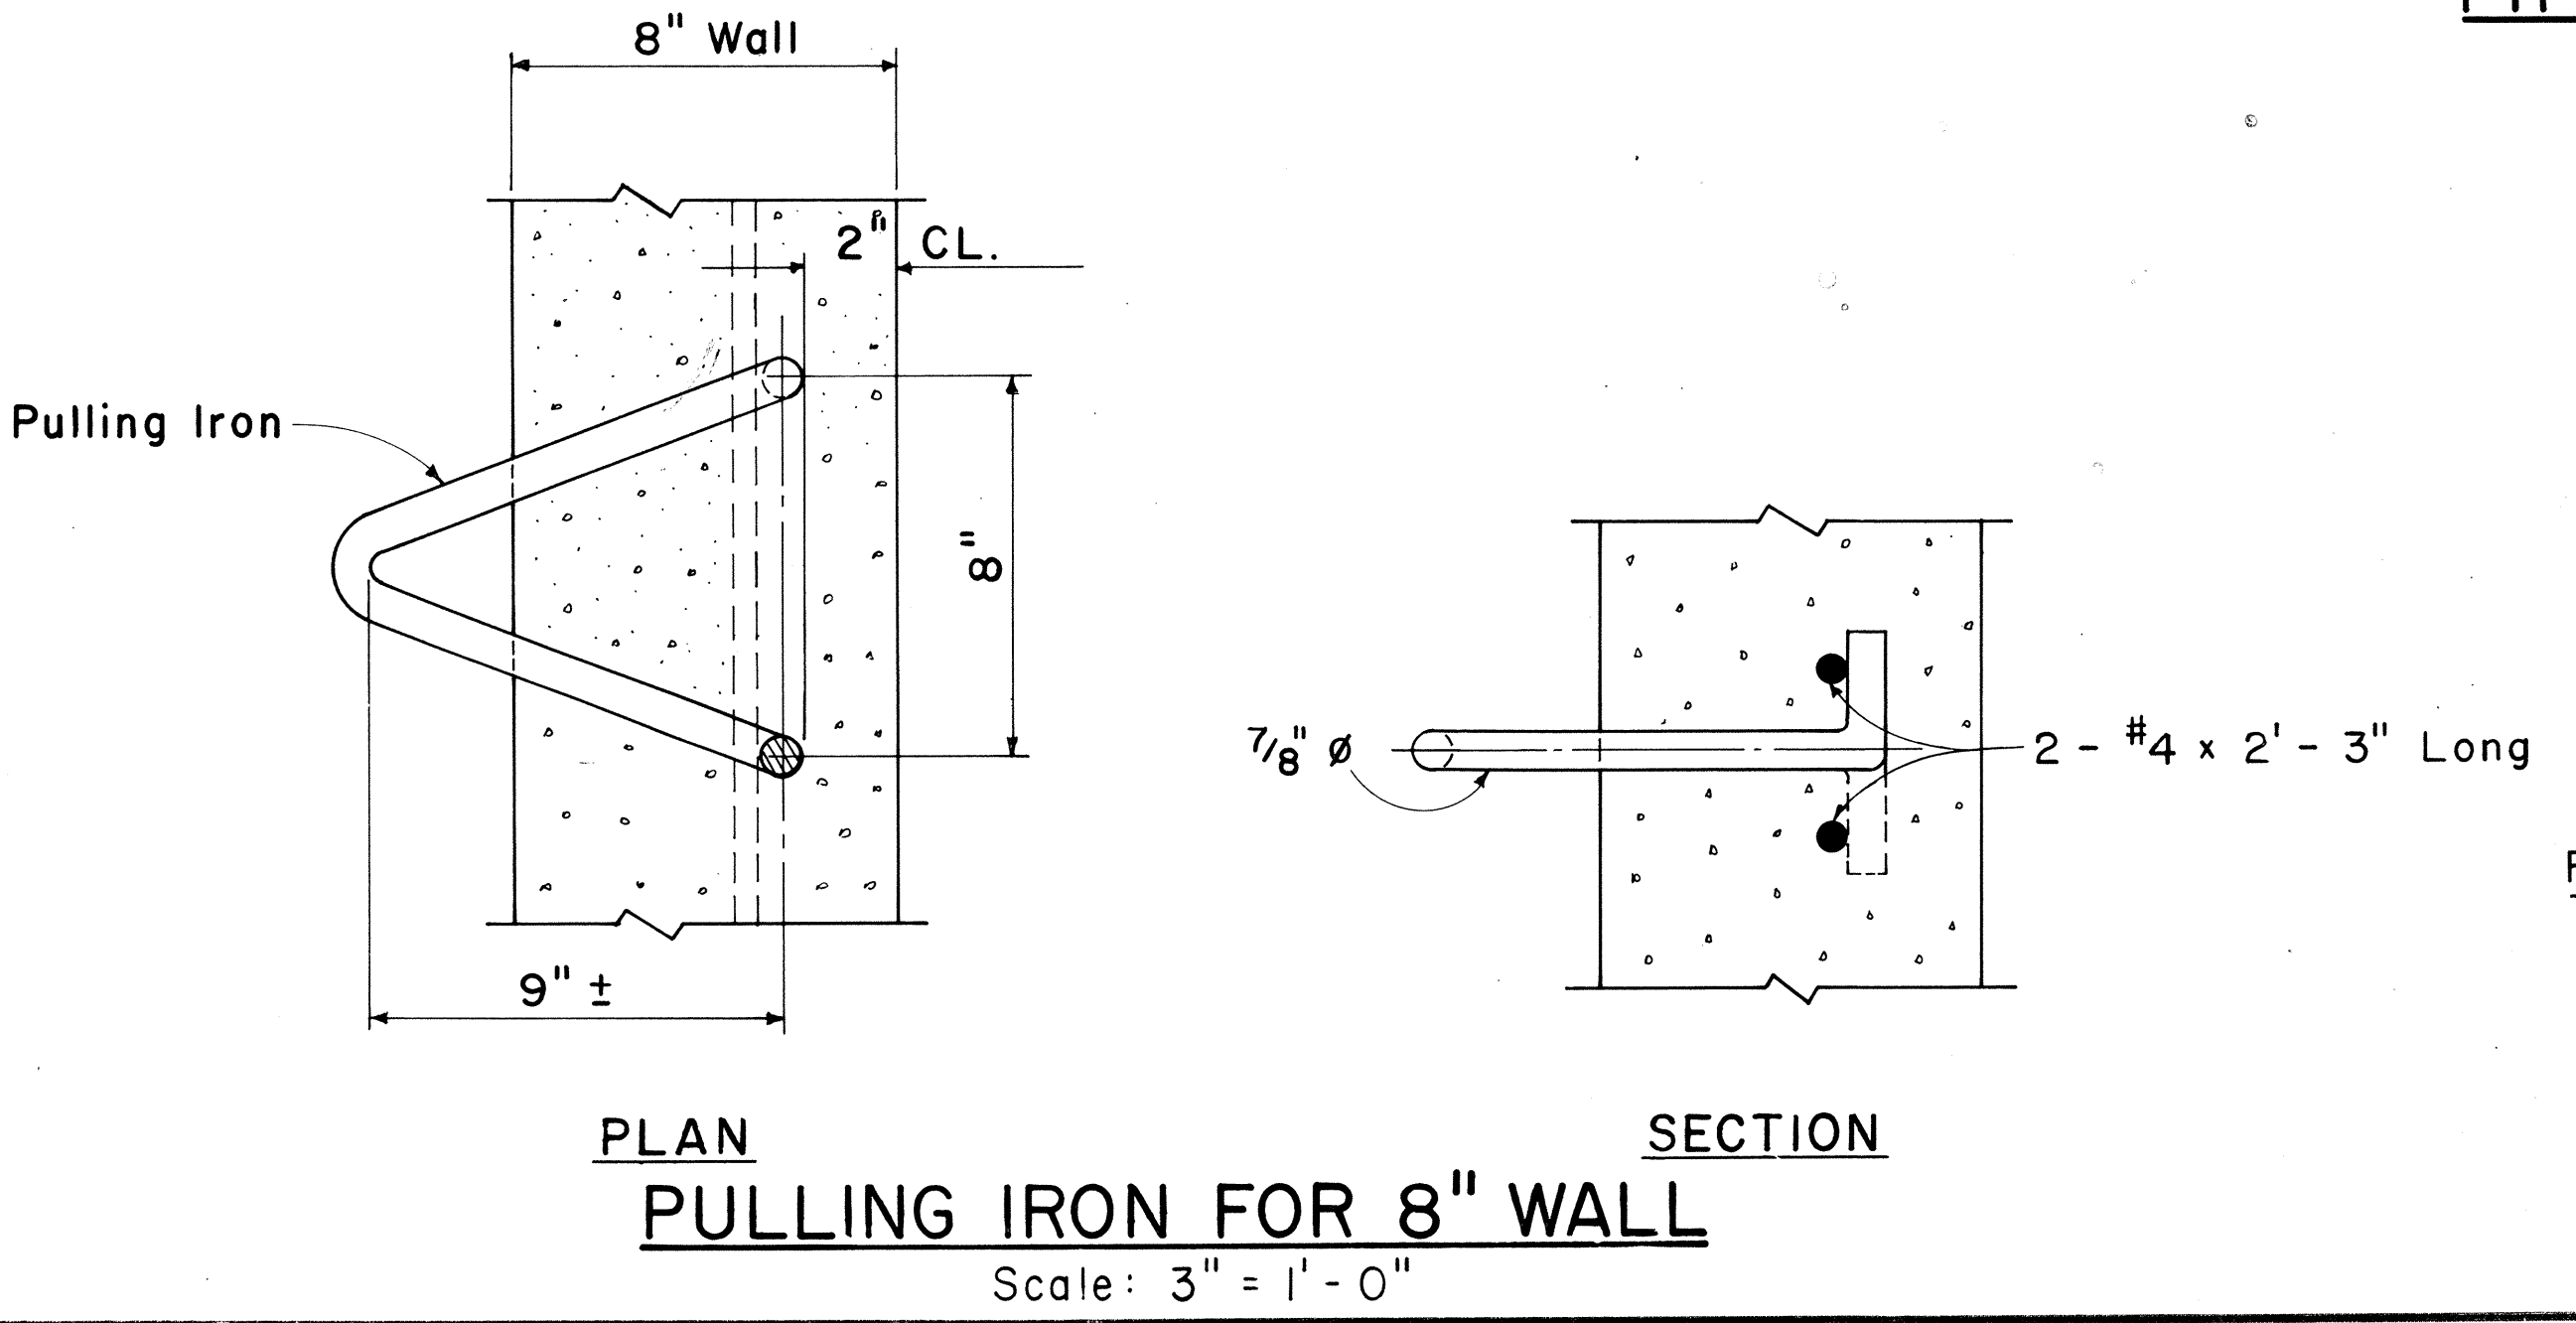

APPROVED: *[Signature]* 2-22-80
Hawaiian Electric Co., Inc. Date

FED. ROAD DIST. NO.	STATE	FED. AID PROJ. NO.	FISCAL YEAR	SHEET NO.	TOTAL SHEETS
HAWAII	HAW.	M-7600(2)	1980	152	244

DD-630.009

HECo., Inc. Drawing Number

16688

SHEET NO. 1 OF 2 SHEETS

STATE OF HAWAII
DEPARTMENT OF TRANSPORTATION
HIGHWAYS DIVISION

MISCELLANEOUS DETAILS
HANDHOLES & MANHOLES
UNDERGROUND STANDARDS

Scale as noted

SHEET No. 2 OF 6 SHEETS

Existing or Finished Grade

Duct line width

See Note 3

Payment width for excavation, sidewalk and pavement.

See Note 2

1'-6" Min.

Unless otherwise shown

Varies

See Note 3

3 Rocks

2 Rocks

See Note 1

3" drainage duct if necessary

Varies

4" 2"

Sanitary Sewer Line.

Concrete poured in place in width of D/L trench.

6"

1/3 of pipe size

6"

Varies

Compacted earth fill or felt cushion.

H.E.Co. duct line

Technical drawing of a tapered wooden handle with the following dimensions and construction notes:

- Overall length: 14"
- Section dimensions (from left to right): 3", 8", 3"
- End view dimensions: 1/2" (width), "A" (height), 1/2" (width)
- Notes:
 - 2 1/2" galv. rd. washers
 - Make eye from 3/8" dia. steel rod and weld to 1/2" dia. rod.
 - Approx. 1" dia.
 - 1/2" dia. steel rod
 - Smooth off all edges on hardwood mandrel and coat with varnish until surface is smooth.
 - Dimension "A" to be 1/2" less than the inside diameter of the specified size conduit.

Diagram illustrating a vertical rod assembly. The rod is labeled $\frac{5}{8}" \phi$ Rod or pipe. The total height of the assembly is 6'-0". The rod is welded to a $\frac{1}{4}"$ Plate. The plate is 3" wide and 4" high. The weld is labeled Weld.

By m9 Wiciso 2-22-80
Hawaiian Electric Co., Inc. Date

PLAN

ELEVATION

Pole

Wood or plastic plug

R.S. or PVC coupling

R.S. conduit (made from 10' length pipe) or PVC bend. Location & number of risers to be determined by project concerned.

3'-0" Min.

1" CL

Top of curb or sidewalk

Use 3' radius bend unless otherwise shown or noted on project plans. Factory bends may be used for duct line run of 15' or less.

1'-6" Tan.

1'-0" Min.

1'-6" Min.

Grounding clamp & ground wire to be supplied & installed by HECO.

Plastic conduit type EB.



Concrete envelope 3" min. cover.

ABS coupling


Adapters (preferred) or 3-bolt clamp (alternate). Attach threaded end of adapter to threaded metal conduit. Solvent weld other end of adapter to plastic conduit. Do not apply solvent cement to threads.

TYPE "A"
TYPICAL CONDUIT ENTRANCE INTO
HANDHOLE, MANHOLE OR VAULT WALLS

HE-37

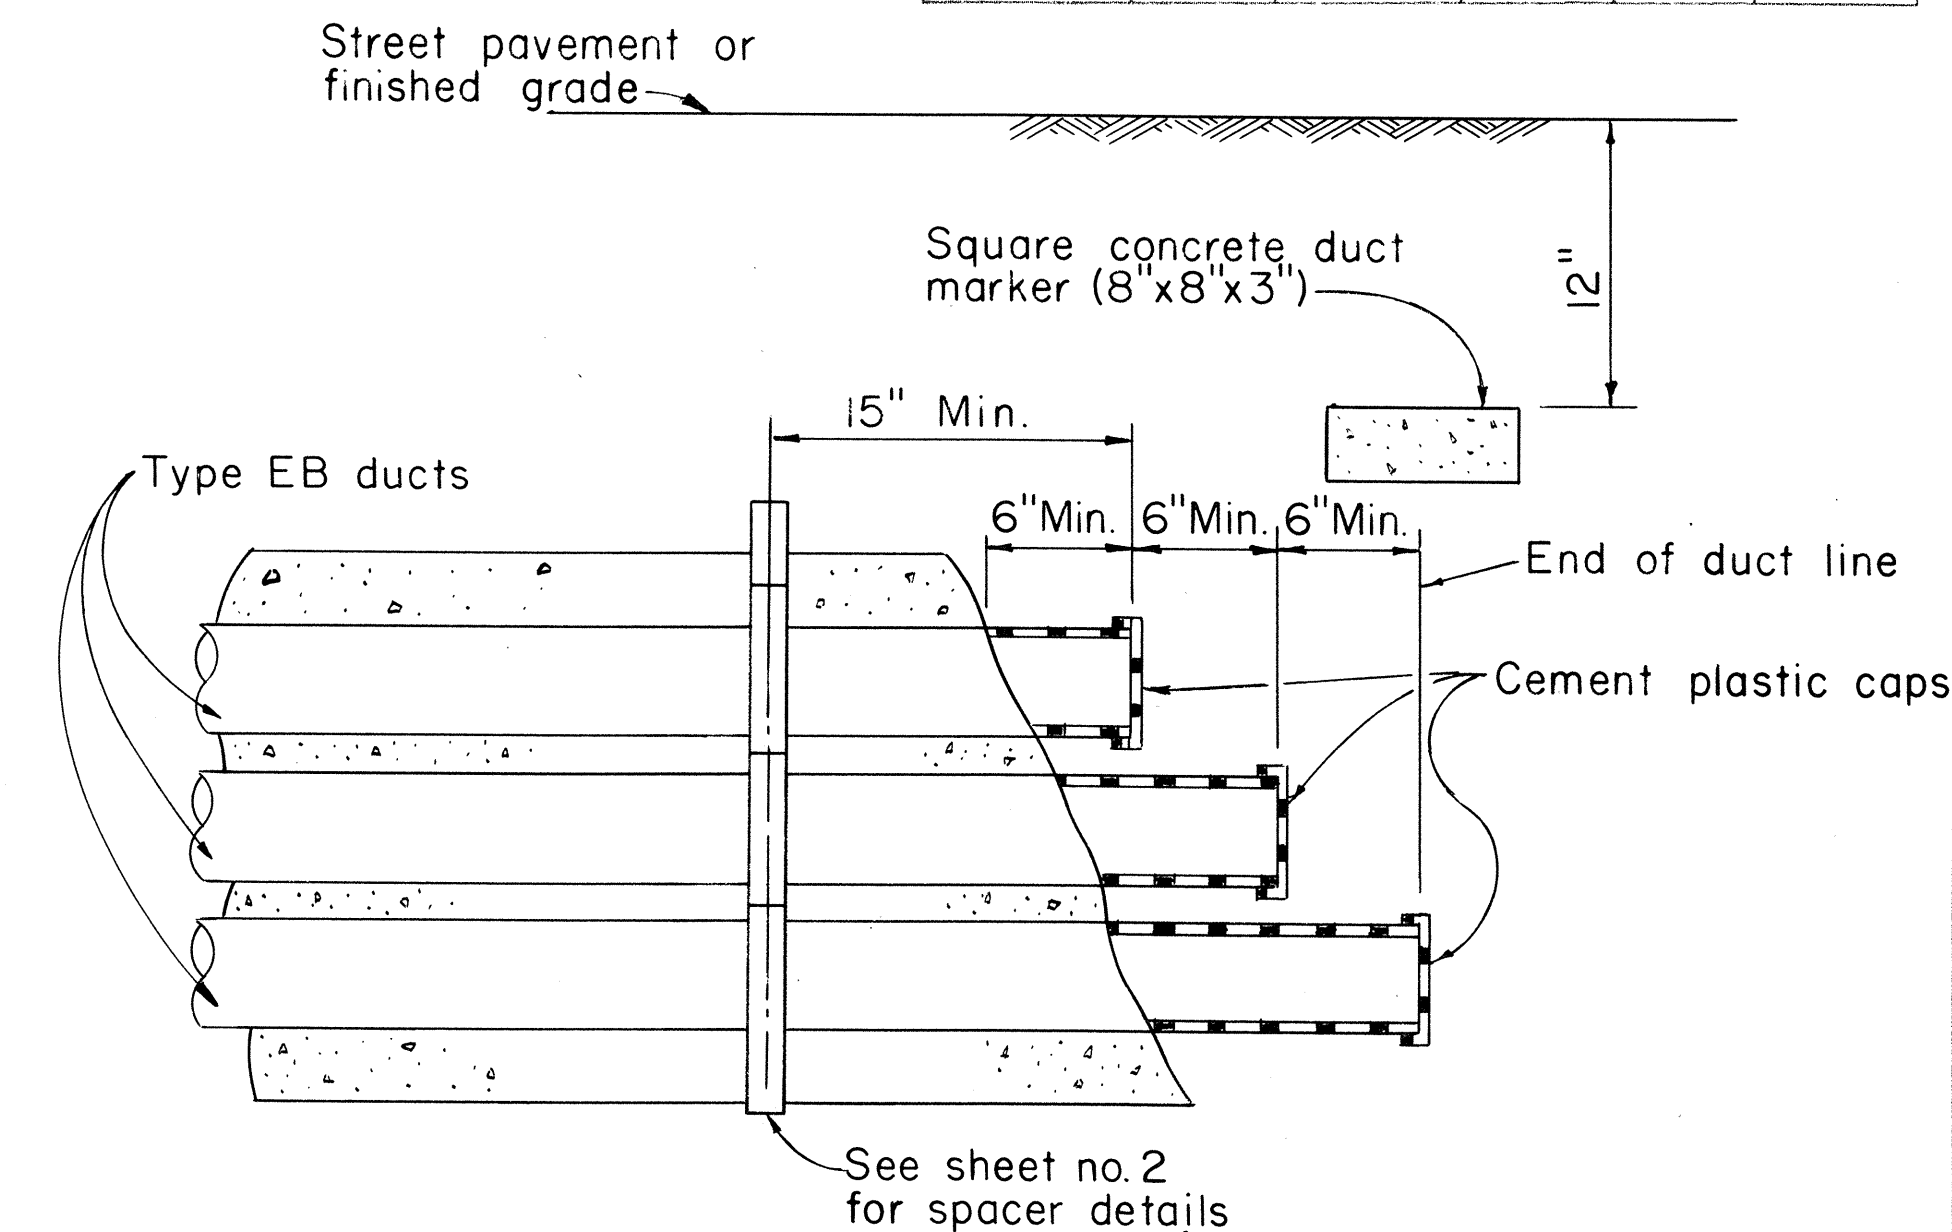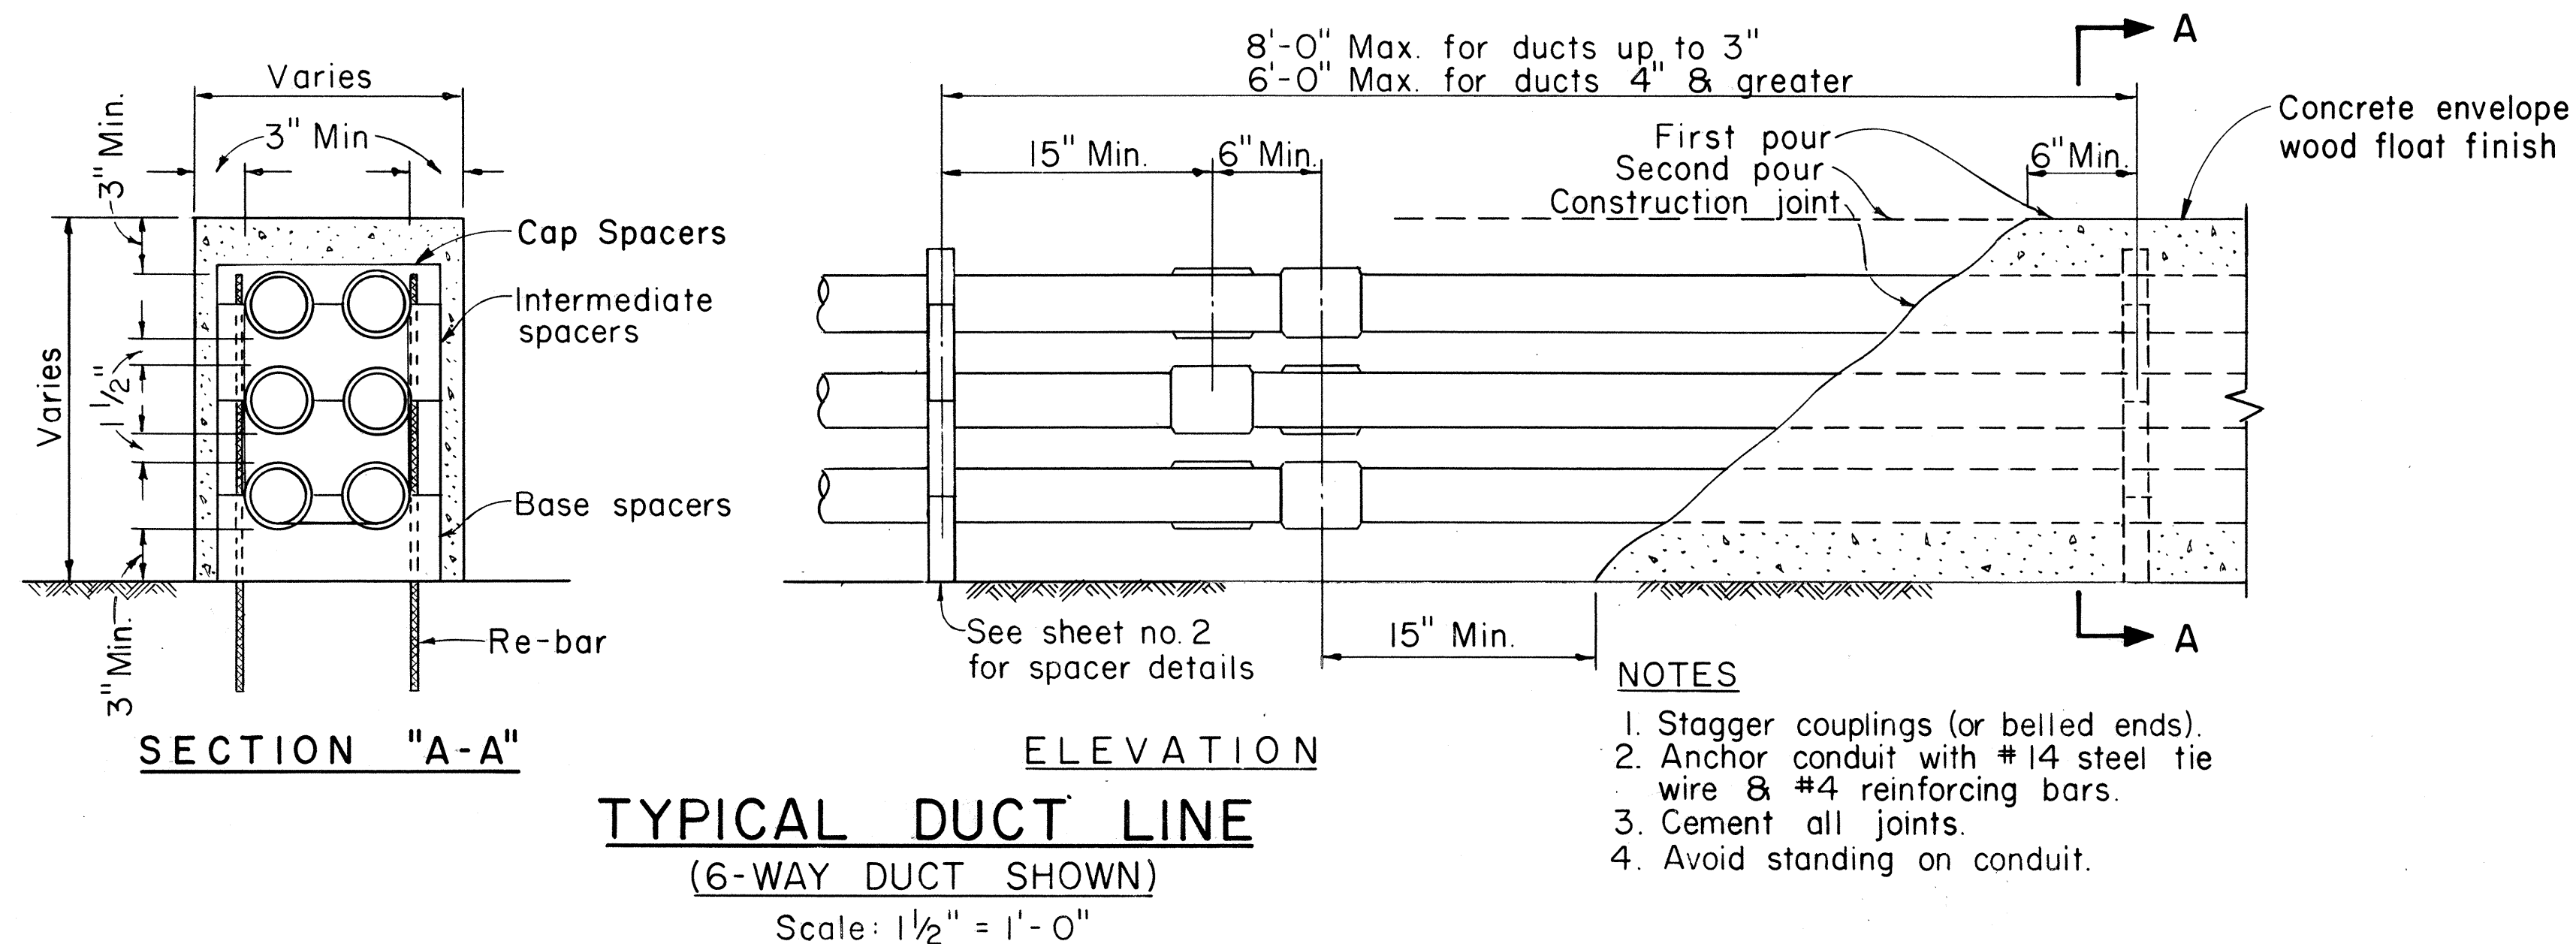


Refer to GO-10 or specific project drawings for depth requirements.

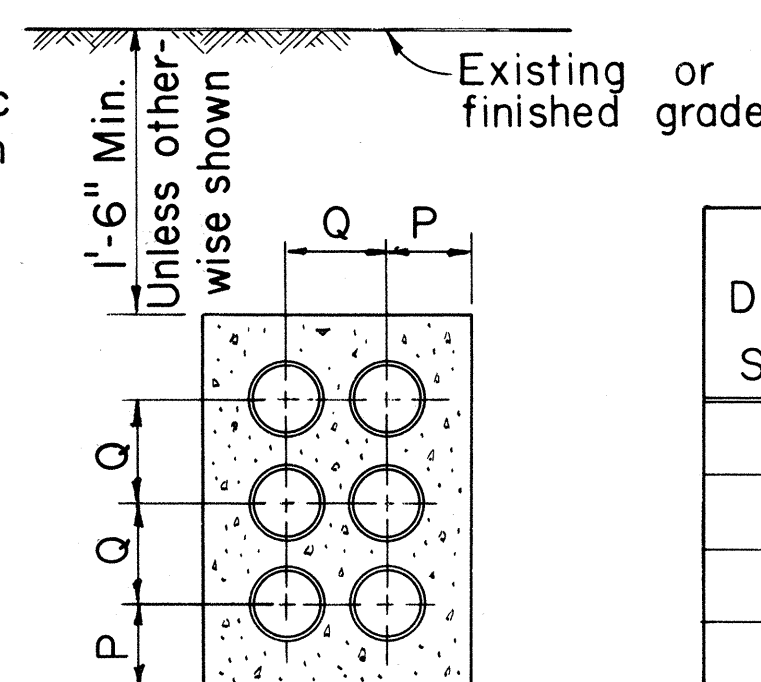

DUCT SIZE	DIMENSIONS (INCHES)	
	P	Q
2	4 1/4	4 1/8
3	4 3/4	5 1/8
4	5 1/4	6 1/4
5	5 7/8	7 5/8
6	6 5/16	8 5/8

TABLE "A"	
APPROX. RADIUS OF BEND, R	LENGTH OF EA. CONDUIT-FT. USING 5° BEND AT COUPL.
11' - 6"	1
17' - 3"	1.5
23' - 0"	2
28' - 9"	2.5
34' - 6"	3
40' - 3"	3.5
46' - 0"	4
51' - 9"	4.5
57' - 6"	5
69' - 0"	6
80' - 6"	7
92' - 0"	8

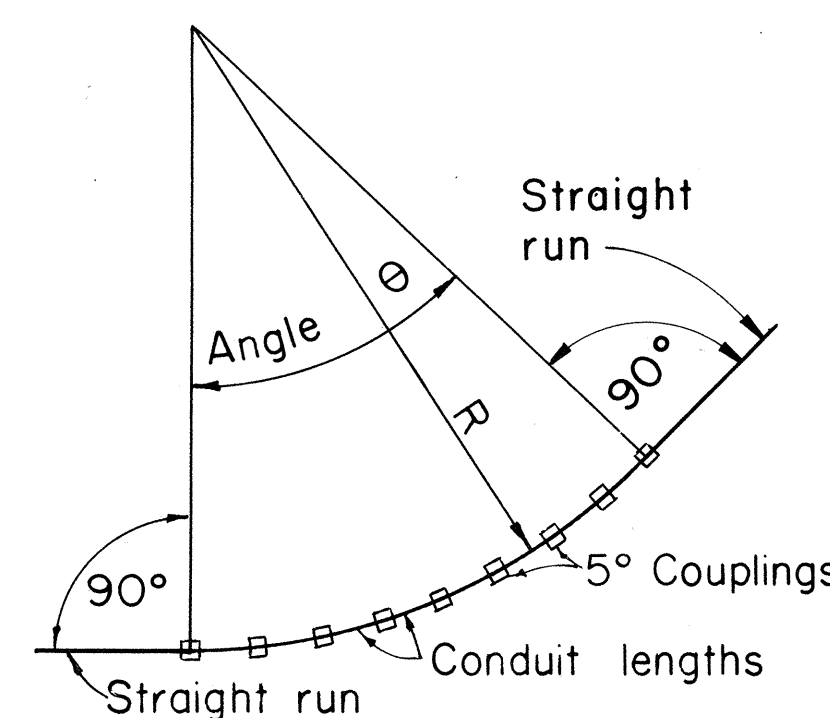

EXAMPLE:

Radius of bend (R) = 60'

Angle of bend (θ) = 45°

From Table A, the nearest value to 60' radius is 57'-6". Length of conduit = 5'.

From Table B, for 45° angle.

Number of couplings required = 9

Number of conduit lengths required = 8

TABLE "B"		
ANGLE OF BEND θ	NO. OF COUPLINGS	LENGTH OF CONDUIT
15°	3	2
30°	6	5
45°	9	8
60°	12	11
75°	15	14
90°	18	17

METHOD OF FORMING CURVES:

There are 4 methods of forming curves with plastic conduit.

1. "Cold" bending: Limit trench formed radius sweeps to 25' minimum radius.
2. "Heat" bending: Do not heat bend conduit.
3. 5° angle couplings may be used as shown.
4. Factory made elbows and sweeps may be used only when specified by Engineer.

APPLICATION OF 5° COUPLING FOR LONG RADIUS BENDS

REFERENCE SPECIFICATION

CS 7202 General Conditions
CS 7001 Construction of U.G. Facilities
CS 7003 Construction of Electrical Facilities

APPROVED:
m *Wesley* 2-22-80
Hawaiian Electric Co., Inc. Date


GENERAL NOTES

A. APPROVED CONDUIT MATERIALS

1. Encased Burial (EB) Conduit
 - a) ~~Asbestos Cement, Type I~~ ----- M7005
 - b) ABS (Acrylonitrile-Butadiene-Styrene) Plastic Conduit, Type EB ----- M7001
 - c) PVC (Polyvinyl Chloride) Plastic Conduit, Type EB ----- M7001
 - d) PVC Plastic Conduit, Schedule 40 ----- 116
2. Direct Burial (DB) Conduit
 - a) ABS Plastic Conduit, Type DB ----- M7001
 - b) PVC Plastic Conduit ----- M7001
 - c) PVC Plastic Conduit, Schedule 40 ----- 116

B. This drawing provides details for installing Plastic Ducts (ABS & PVC) only. Refer to drawing 30-1030 & 30-1033 for installing ~~Asbestos Cement Ducts~~ Encased Burial.


HECO PURCHASE SPECIFICATION NO.

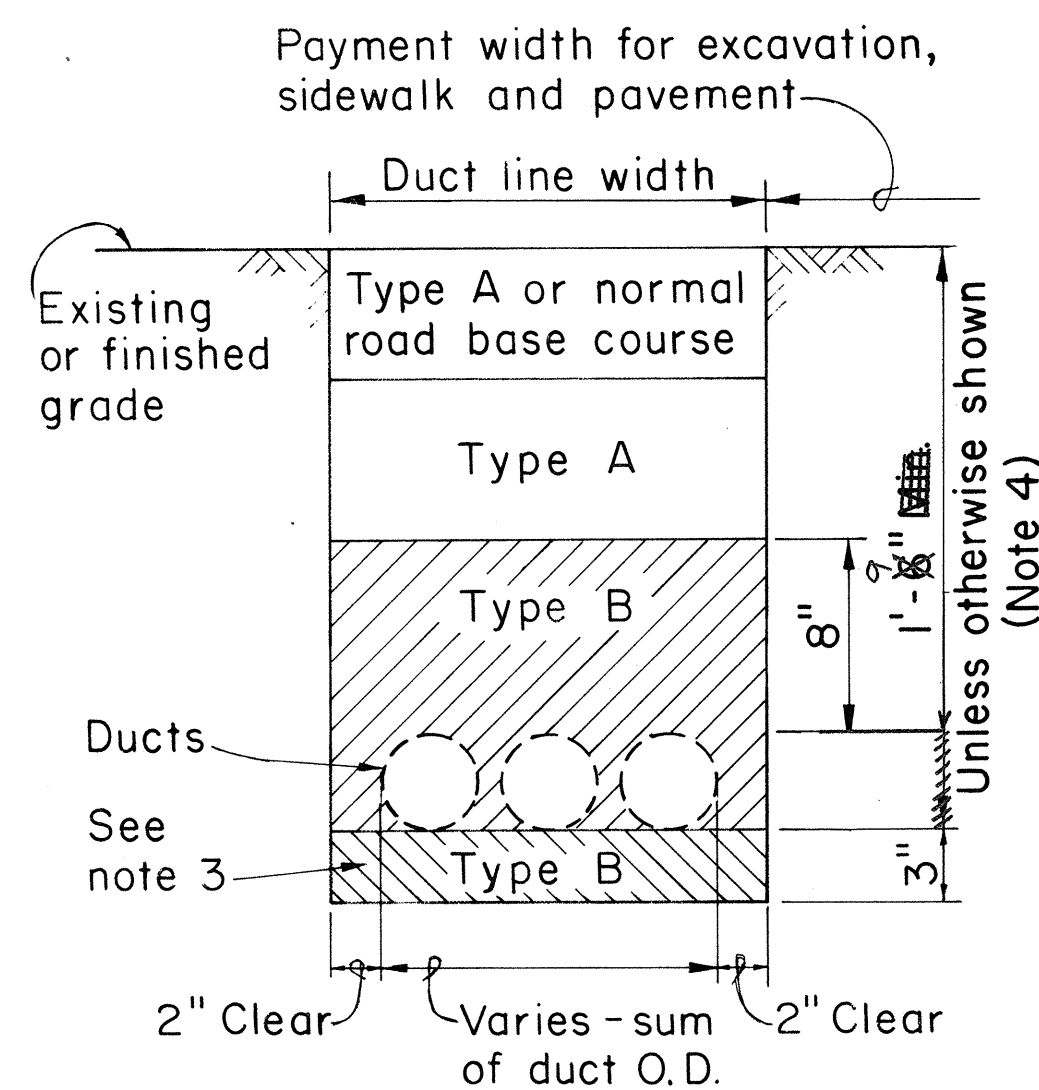

- NOTES:**
1. Type A: Beach sand, earth or earth and gravel. If earth and gravel, the max. rock size shall be 1" and the mixture shall contain not more than 50%, by volume, of rock particles.
 2. Type B: Beach sand, earth or earth and gravel. If earth and gravel, the mixture must pass a 1/2" mesh screen and contain not more than 20%, by volume, of rock particles.
 3. When trench bottom is coarser than Type B material, provide 3" duct cushion.
 4. Refer to GO-10 or specific project drawings for depth requirements.



DD-630.005

HECO., Inc. Drawing Number	
30-1035	SHEET No. 1 OF 2 SHEETS
STATE OF HAWAII DEPARTMENT OF TRANSPORTATION HIGHWAYS DIVISION	
STANDARD DETAILS	
PLASTIC DUCTS INSTALLATION DETAILS UNDERGROUND STRUCTURES	
Scale as noted	
SHEET No. 5 OF 6 SHEETS	

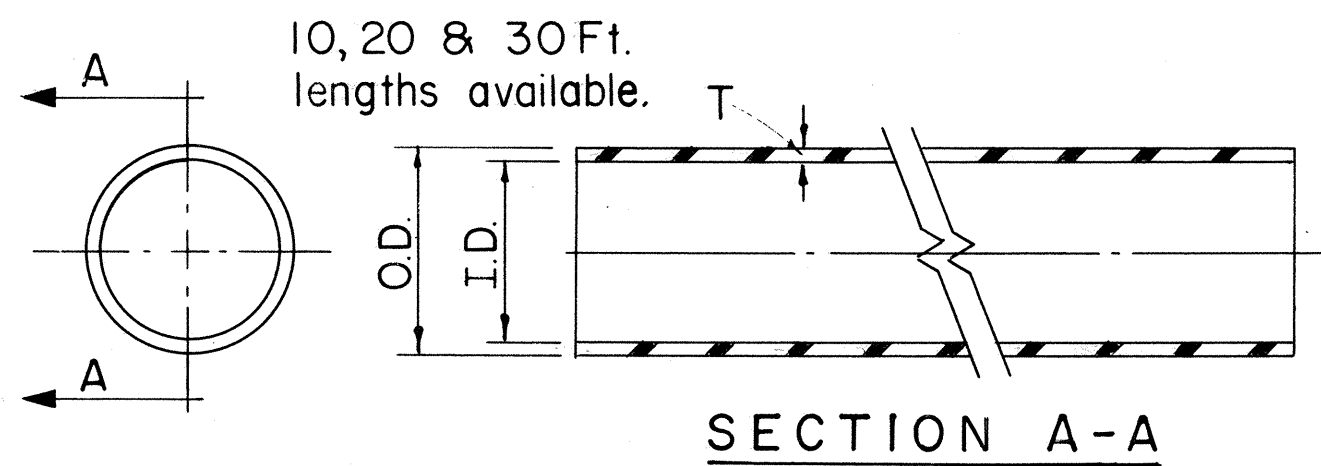



SECTION A-A

CONDUIT

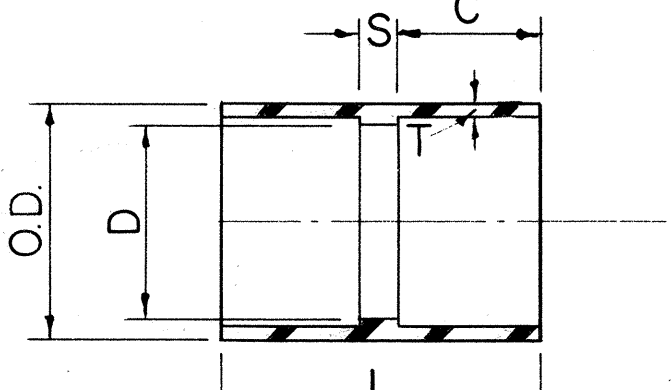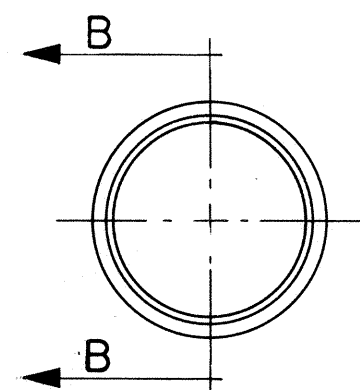


SECTION B-B

COUPLING (ASTM D-2750)

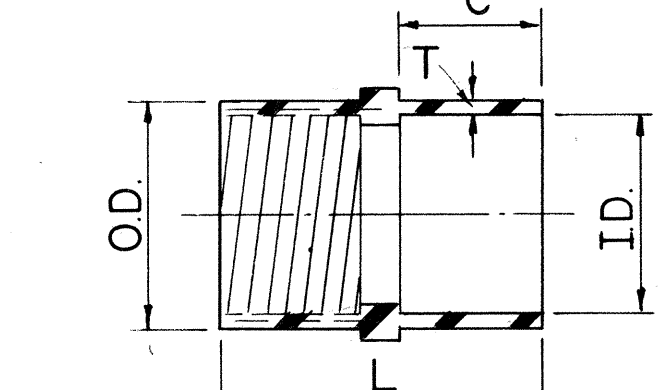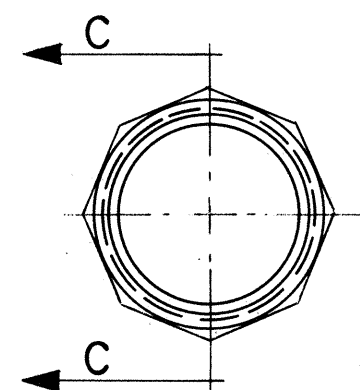


SECTION C-C


ADAPTER - PLASTIC TO STEEL

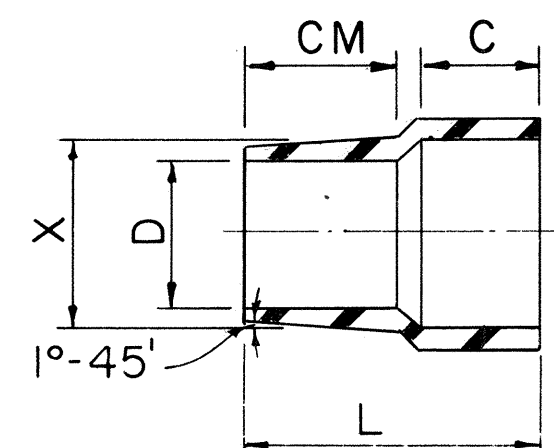

ADAPTER - PLASTIC TO ASBESTOS CEMENT

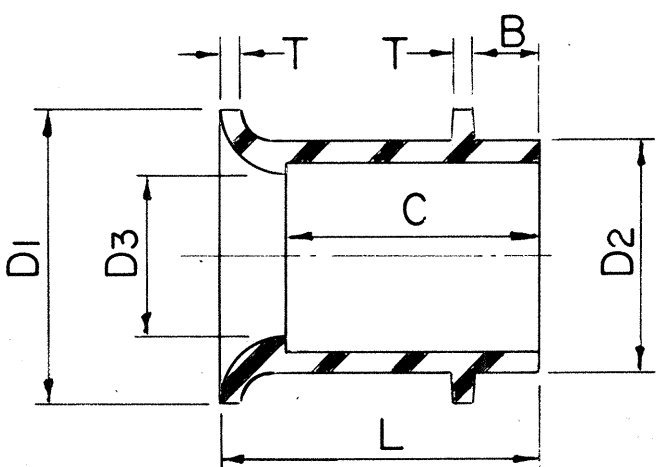


END BELL (ASTM D-2750)

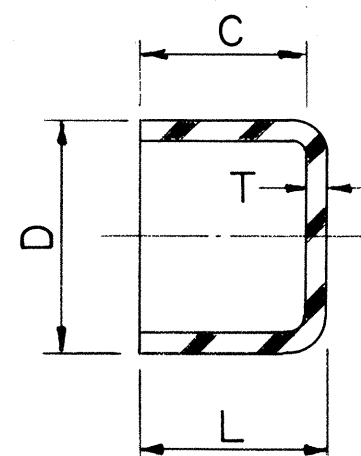

CAP (RIGID) - FOR SEMI-PERMANENT USE (ASTM D-2750)

SIZE	HECO CODE	D	C	L	T
2		2.52	.59	.65	.060
3		3.68	.81	.89	.075
4		4.725	.91	1.01	.095
5		5.805	1.00	1.10	.100
6		6.920	1.13	1.25	.125

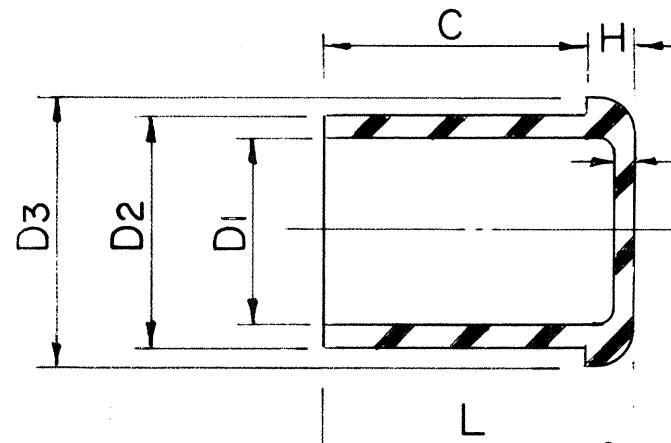

CAP (TEMPORARY) (ASTM D-2750)

CONDUIT SIZE	EB (ENCASED BURIAL)					DB (DIRECT BURIAL)				
	HECO CODE	O.D.	I.D.	T (MIN.)	WEIGHT #/10 ² FT.	HECO CODE	O.D.	I.D.	T (MIN.)	WEIGHT #/10 ² FT.
2		2.375	2.25	.060	21	29010	2.375	2.15	.110	38
3		3.500	3.35	.075	39	29012	3.500	3.25	.125	64
4		4.500	4.31	.095	63	29014	4.500	4.18	.160	104
5		5.563	5.36	.100	82	29016	5.563	5.20	.180	146
6		6.625	6.375	.125	121		6.625	6.25	.190	182


NOTE: Type EB & DB Conduits have same O.D. for a given size. All fittings which go over Conduits are DB type & fit both types of Conduits.

SIZE	HECO CODE	O.D.	D	L	C	S	T
2		2.620	2.255	2 7/16	1.16	.110	.110
3		3.780	3.350	3 3/8	1.63	.120	.125
4		4.855	4.310	3 11/16	1.78	.120	.160
5		5.965	5.363	4 3/32	1.97	.160	.180
6		7.050	6.375	4 15/32	2.16	.160	.190

SIZE	HECO CODE	O.D.	I.D.	L	T	C
2				2 15/16	1 1/16	1.16
3				3 7/16	1 5/8	1.63
4				3 11/16	1 23/32	1.78
5				4 1/16	1 27/32	1.97
6				15 5/8	1 11/16	3.44


SIZE	HECO CODE	L	X	C.M.	D	C
2		3 1/16	2.580	1 3/4	2.18	1.16
3		3 19/32	3.620	1 3/4	3.09	1.63
4		4 1/32	4.620	2	4.03	1.78
5						

SIZE	HECO CODE	D1	D2	D3	B	C	L	T
2		3.01	2.520	2.255	.50	1.16	1.54	.060
3		4.10	3.680	3.350	.75	1.63	2.00	.075
4		5.31	4.725	4.310	.75	1.78	2.28	.095
5		6.36	5.805	5.363	1.00	1.97	2.47	.100
6		7.38	6.920	6.375	1.00	2.16	2.66	.125

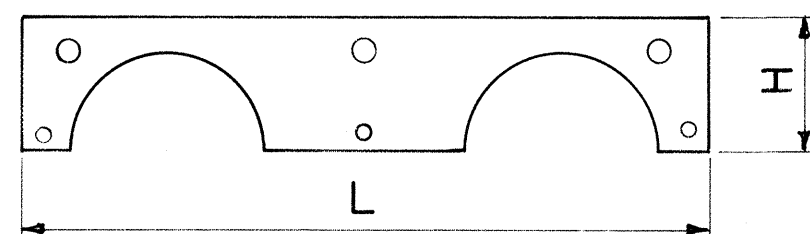


SIZE	HECO CODE	L	H
2		9.50	1.75
3		11.25	2.25
4		13.75	3.13
5		15.87	3.63
6		18.0	4.25

CAP SPACER

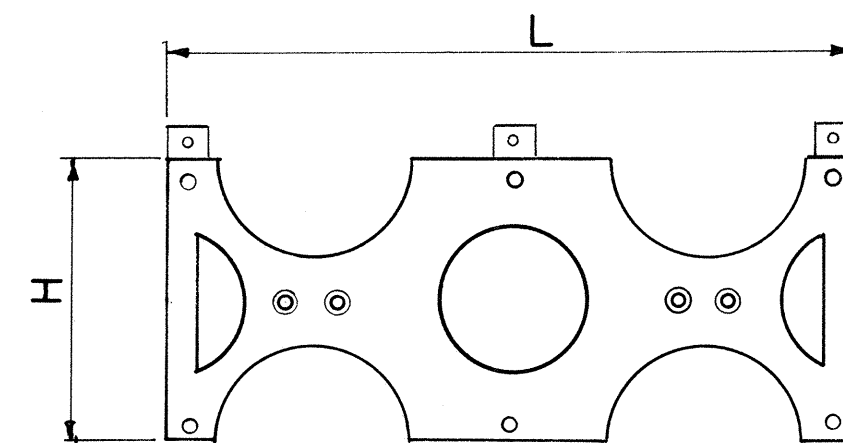


INTERMEDIATE SPACER

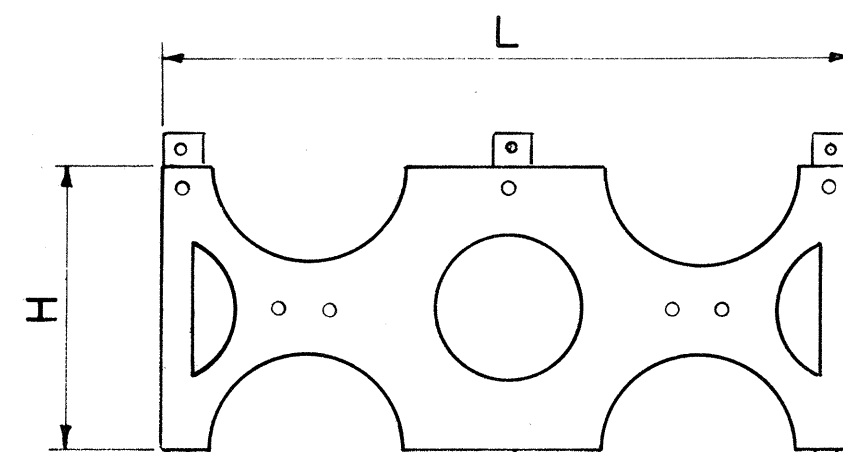

BASE SPACER

DUCT SPACER COMPONENTS (FORMEX SPACER OR EQUIVALENT)

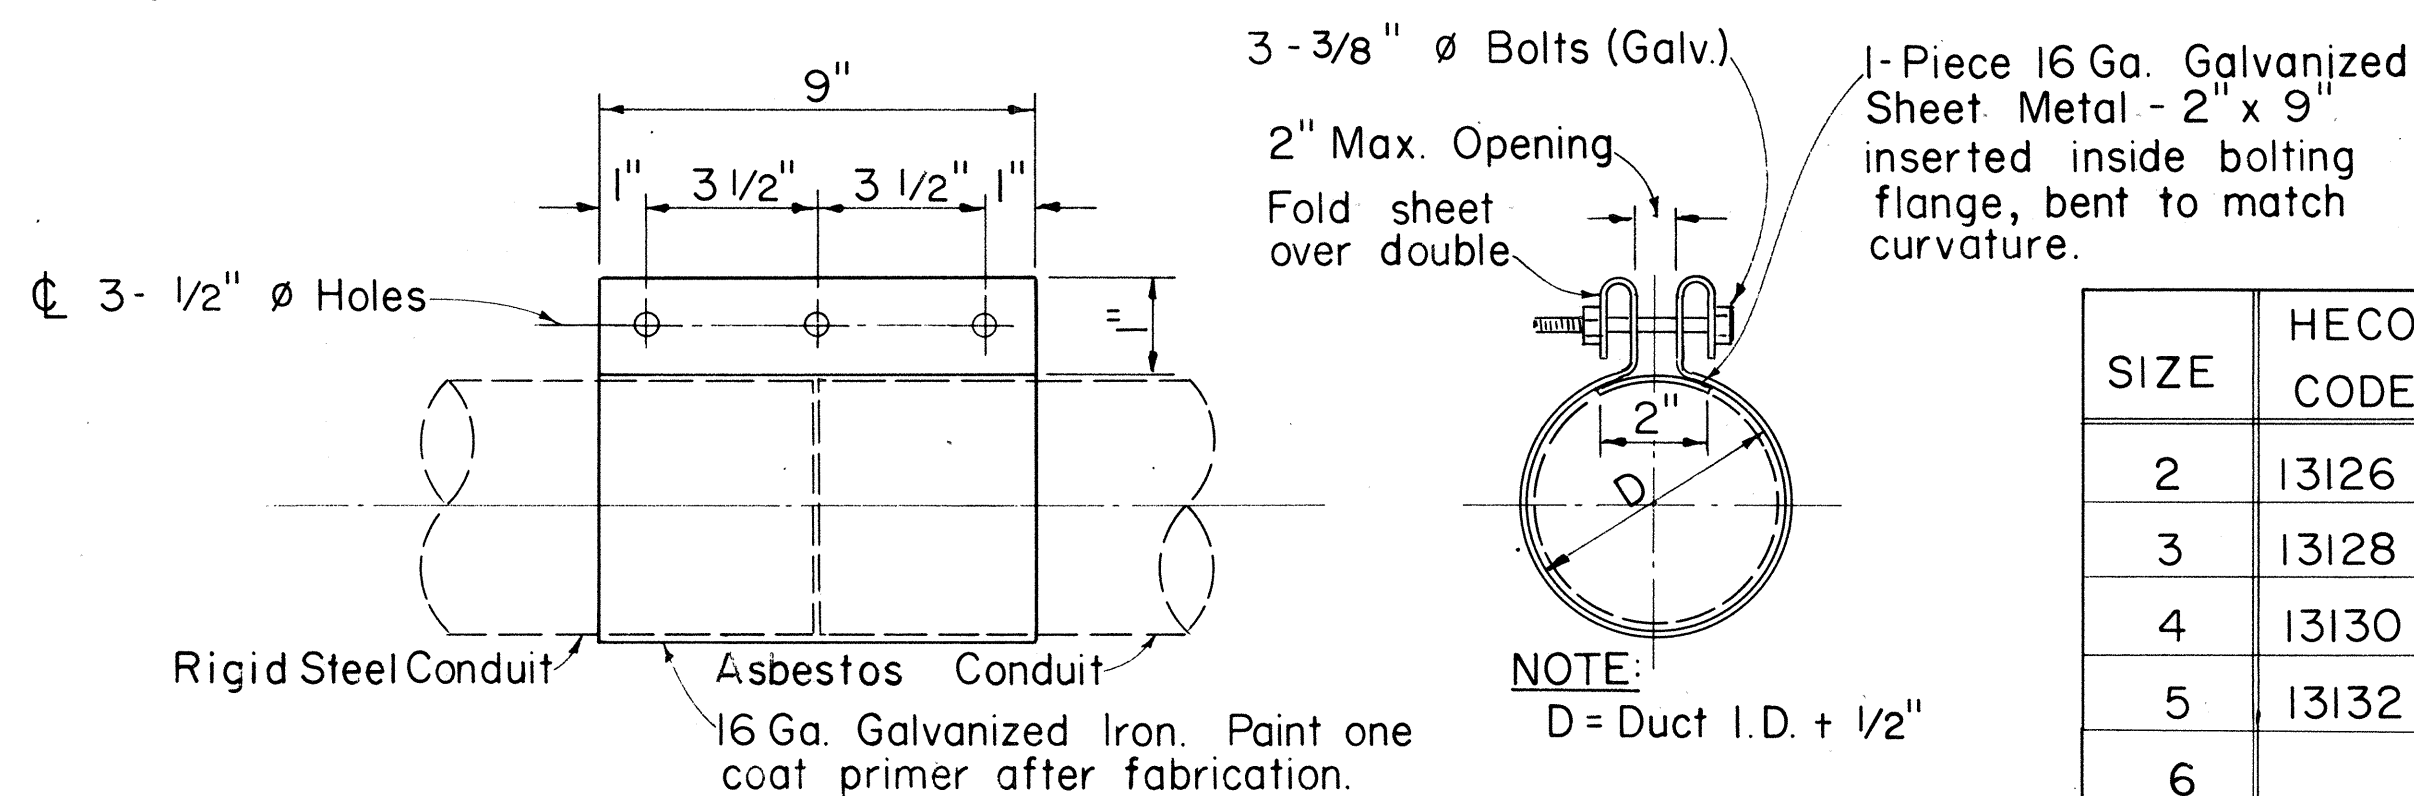

3 - BOLT CLAMP

GENERAL NOTES:

1. All dimensions in inches.
2. Spacers shown are different than that used for Asbestos Cement Type.
3. These accessories are to be used with ABS (Acrylonitrile-Butadiene - Styrene), or PVC (Poly-Vinyl Chloride) Plastic Conduit, per HECO purchase specification M7001-O.

APPROVED: *[Signature]* 2-22-80
Hawaiian Electric Co., Inc. Date

SIZE	HECO CODE	D1	D2	D3	C	H	L	T
2		2.260	2.375	2.500	.593	.125	.718	.060
3		3.360	3.500	3.656	.812	.156	.968	.075
4		4.320	4.500	4.687	.906	.187	1.092	.095
5		5.375	5.638	5.760	1.000	.218	1.218	.100
6		6.390	6.625	6.875	1.093	.250	1.343	.125

NOTE: Cap will go over conduit or "plug" the coupling.

FED. ROAD DIST. NO.	STATE	FED. AID PROJ. NO.	FISCAL YEAR	SHEET NO.	TOTAL SHEETS
HAWAII	HAW.	M-7600(12)	1980	156	244

SIZE	HECO CODE	L	H	W
2		9.50	3.94	
3		11.25	5.06	
4		13.75	6.06	
5		15.97	7.06	
6		18.0	8.19	

SIZE	HECO CODE	L	H
2		9.50	4.25
3		11.25	4.75
4		13.75	5.25
5		15.87	5.87
6		18.0	6.375

SIZE	HECO CODE
2	13126
3	13128
4	13130
5	13132
6	

DD-630.006

HECo., Inc. Drawing Number

30-1035

SHEET NO. 2 OF 2 SHEETS

STATE OF HAWAII
DEPARTMENT OF TRANSPORTATION
HIGHWAYS DIVISION

STANDARD DETAILS
PLASTIC DUCTS
INSTALLATION DETAILS
UNDERGROUND STRUCTURES

Scales: Not to Scale

SHEET No. 6 OF 6 SHEETS