	INDEX TO DRAWINGS
SHEET NO.	DESCRIPTION
· · · · · · · · · · · · · · · · · · ·	TITLE SHEET
2	ELEC, SYMBOLS & NOTES
3	ONE-LINE DIAGRAM & MISC, ELEC, DET.
4	HIGHWAY LIGHTING PLAN
5	HWY LTG STANDARD DETAIL
6 · · · · 6	SLIP BASE INSERT DETAIL
	STANDARD DETAIL PULLBOXES
	v.
·	
,	
,	

**★** 3S-I

NEW TOTAL = 8

959

STATE OF HAWAII

## DEPARTMENT OF TRANSPORTATION HIGHWAYS DIVISION


HONOLULU, HAWAII


"AS-BUILT"

PLANS FOR

## KAMEHAMEHA HIGHWAY, HIGHWAY LIGHTS

CASTLE JUNCTION TOWARDS HALEKOU I.C.
FEDERAL AID PROJECT NO. FR-083-1(21)
DISTRICT OF KOOLAUPOKO
ISLAND OF OAHU

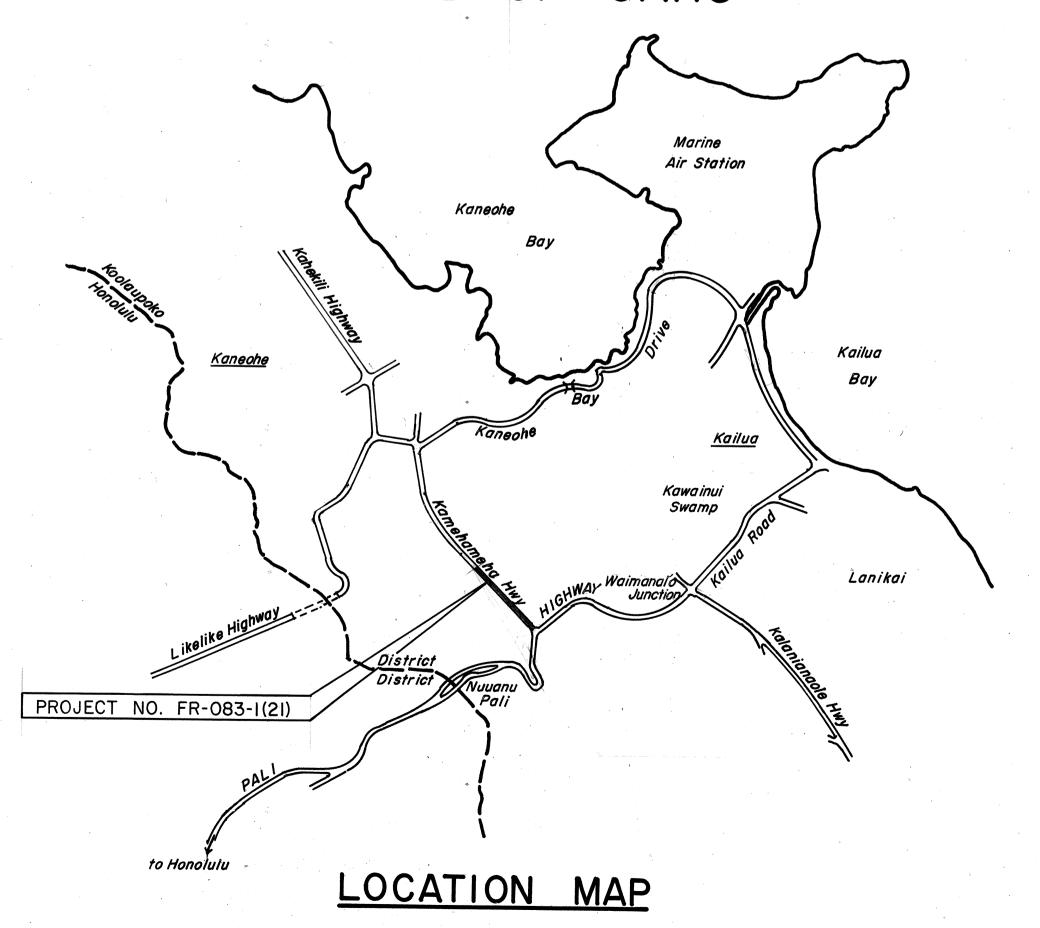

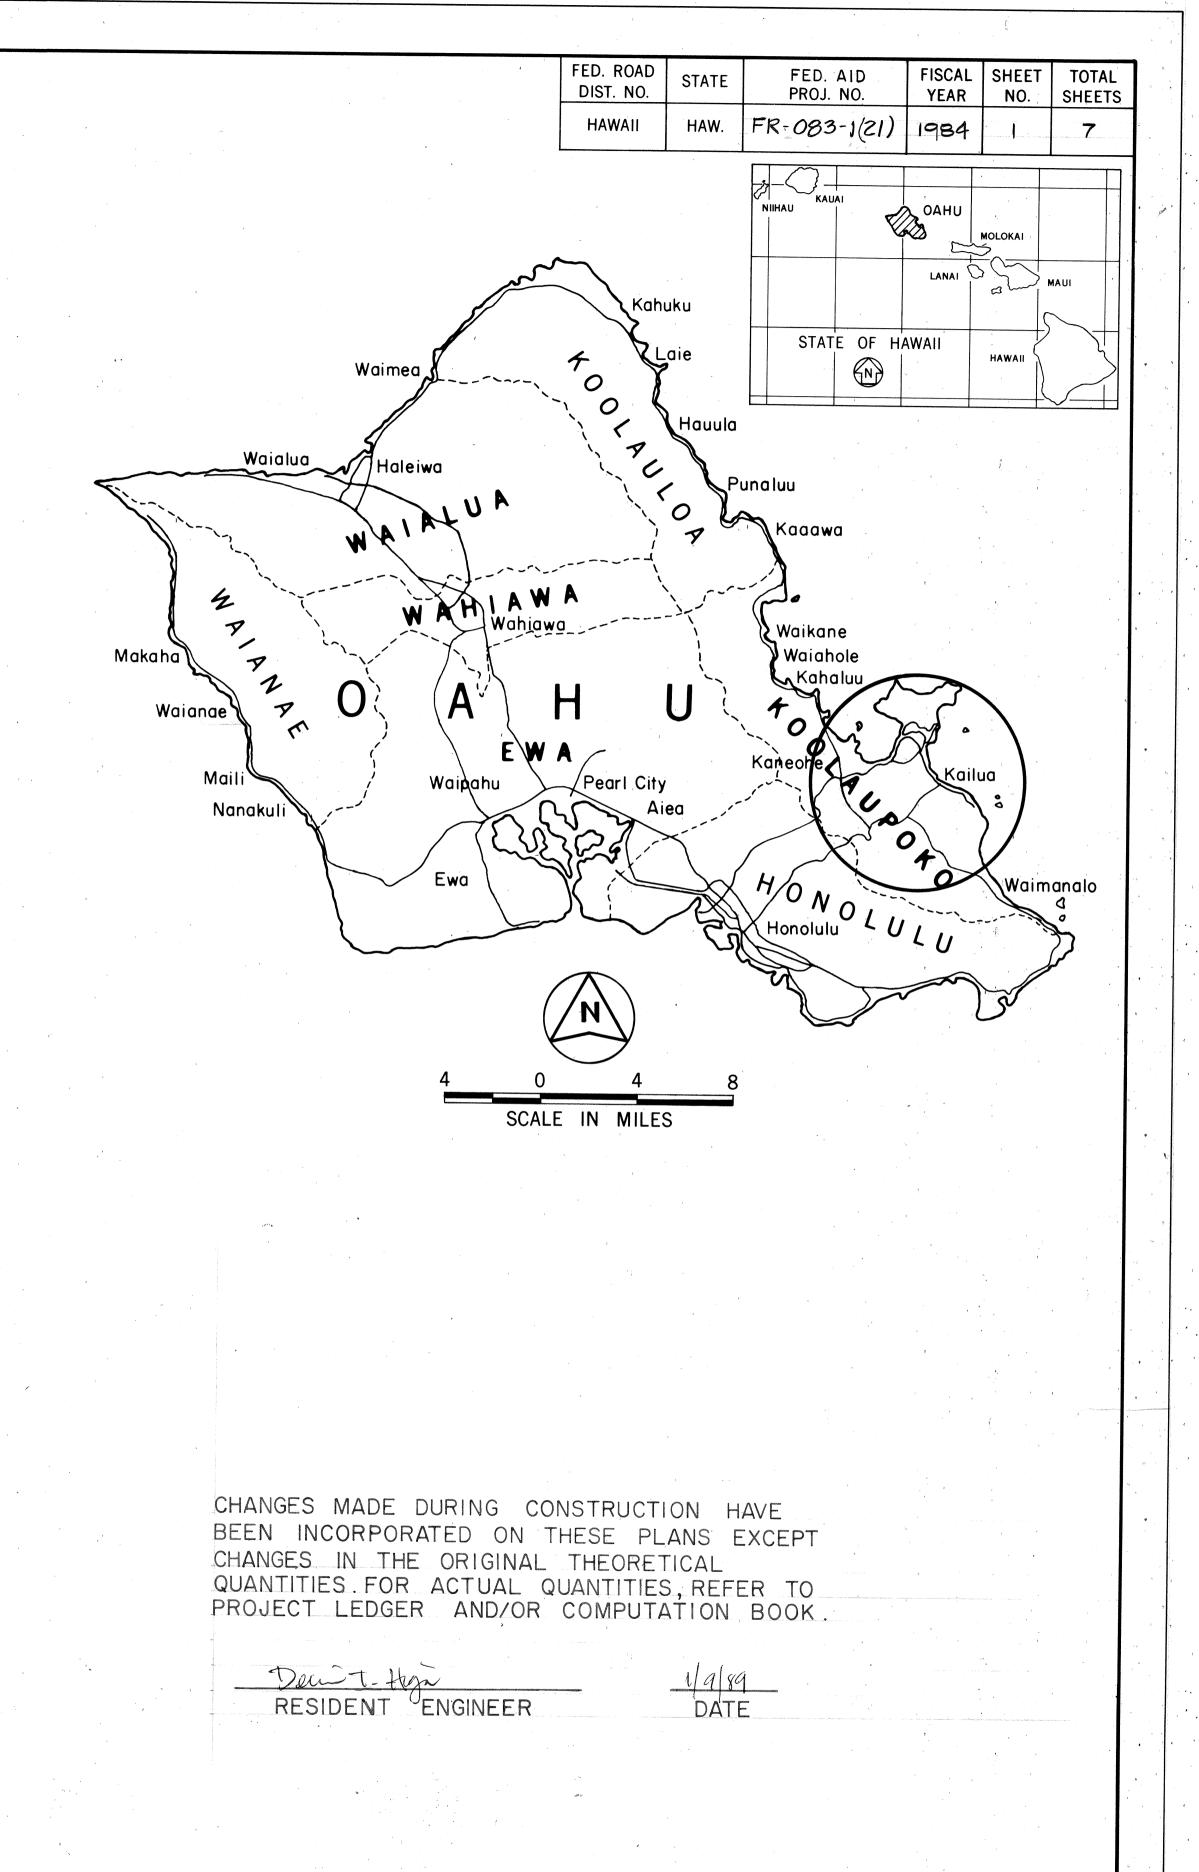

URA, KAWABATA \$4550C, FRED ABESHIMA 548-4042 MARCH 1983
DESIGNED BY P. S. & E. BY PHONE DATE

DEPARTMENT OF TRANSPORTATION
FEDERAL HIGHWAY ADMINISTRATION

APPROVED:
DIVISION ADMINISTRATOR

DATE

DEPARTMENT OF TRANSPORTATION
STATE OF HAWAII

APPROVED:

Chuy Q. Soon July 5/98
JODIR. OF TRANSPORTATION BATE