,	/
11	NDEX TO DRAWINGS
SHEET NO.	DESCRIPTION
1	TITLE SHEET
2-11	TYPICAL SECTION, PLAN AND STANDARD DETAILS
12-14	DRAINAGE DETAILS AND STANDARD DETAILS
15 - 23	SIGNING, LANDSCAPING ANI STRIPING PLANS AND STANDARD DETAILS
24 - 27	HIGHWAY LIGHTING PLANS
	A
,	
	-





## HAWAII

DEPARTMENT OF TRANSPORTATION HIGHWAYS DIVISION


> HONOLULU, HAWAII "AS-BUILT" PLANS FOR


FARRINGTON HIGHWAY SAFETY IMPROVEMENTS, VICINITY OF PALAILAI INTERCHANGE

FEDERAL AID PROJECT NO. F-093-I(I)

DISTRICT OF EWA ISLAND OF OAHU

SCALE I INCH = 100 FEET PLAN

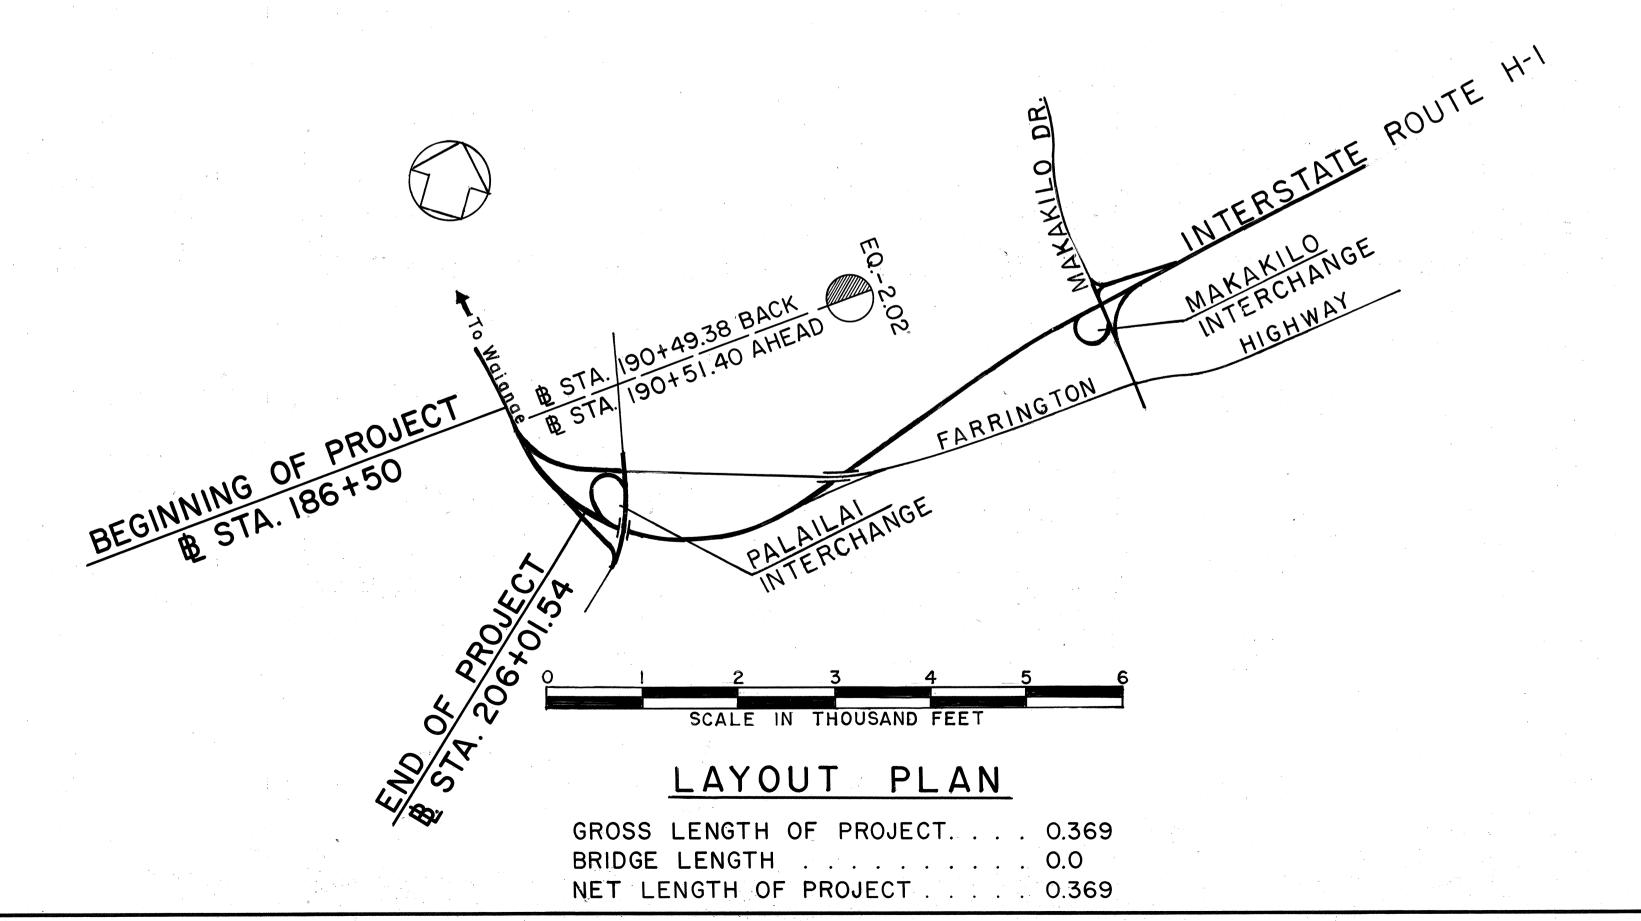

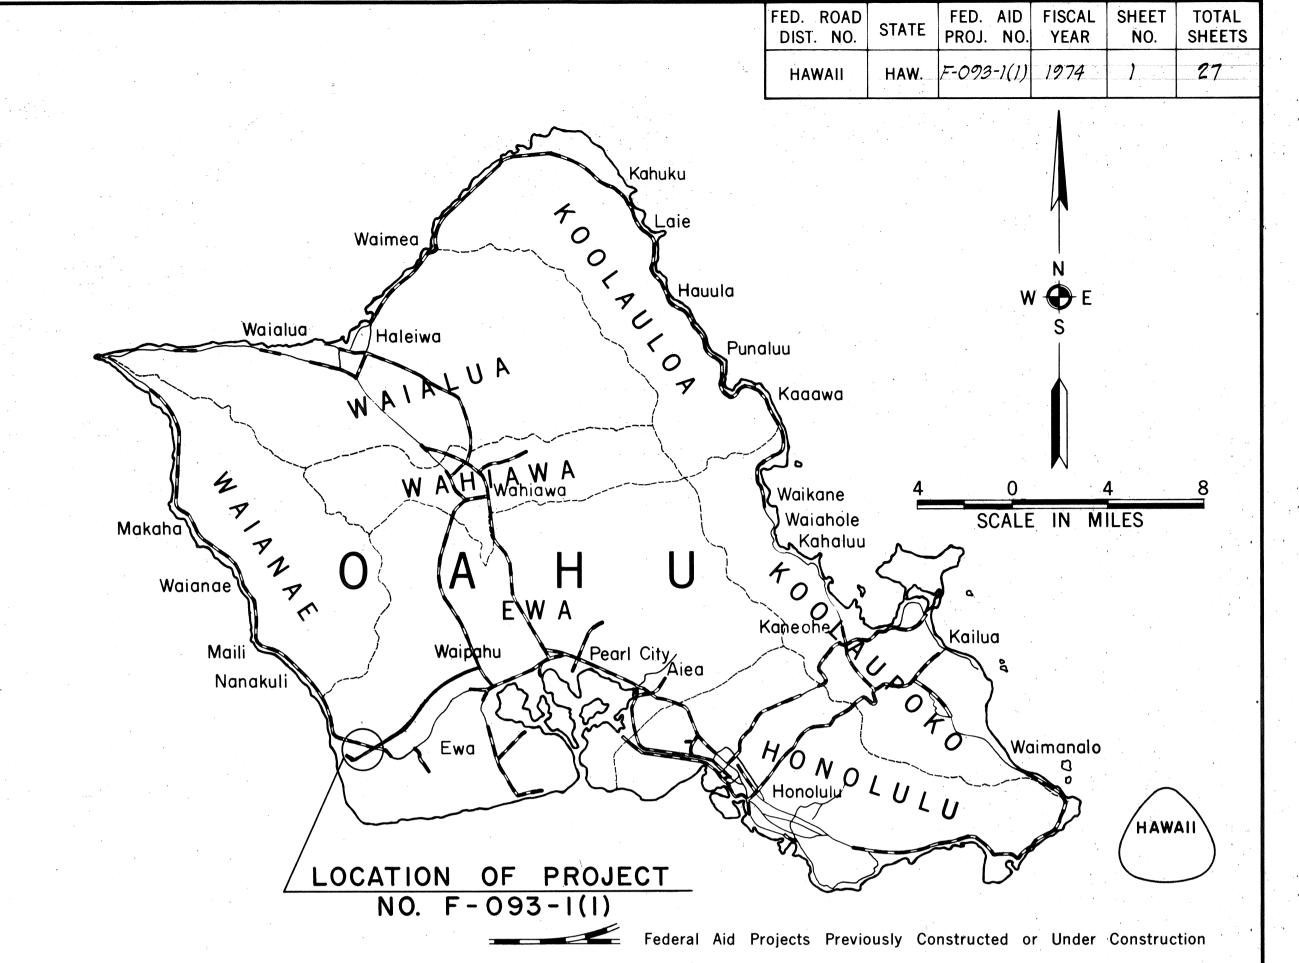

## DESIGN CLASSIFICATION

ADT (1974). . . . . . . 18,100 DESIGN ADT (1994) . . . 29,500 V . . . . . . . . . . . 60 M.P.H.

ALL CHANGES MADE DURING CONSTRUCTION HAVE BEEN INCORPORATED ON THESE PLANS EXCEPT CHANGES IN THE ORIGINAL THEORETICAL QUANTITIES.

PROJECT ENGINEER

DEPARTMENT OF TRANSPORTATION FEDERAL HIGHWAY ADMINISTRATION 11.8.73

DATE

DEPARTMENT OF TRANSPORTATION STATE OF HAWAII APPROVED: