	INDEX TO DRAWINGS
SHEET NO.	DESCRIPTION
1	TITLE SHEET
2	GENERAL SITE and SHEET LAYOUT PLAN
3	SECTIONS "A" & "B" ELECTRICAL PLANS
4	SECTIONS "C" & "D" ELECTRICAL PLANS
5	TYPICAL STREET LIGHT and MISCELLÂNEOUS DETAILS
vor,	
	,





DEPARTMENT OF TRANSPORTATION

HIGHWAYS DIVISION

HONOLULU, HAWAII

"AS BUILT"


PLANS FOR
HIGHWAY LIGHTING IMPROVEMENT
OF


FARRINGTON HIGHWAY

PILIOKOE STREAM TO NANAKULI AVE.

PROJECT NO. 93A-02-83

DISTRICT OF WAIANAE
ISLAND OF OAHU

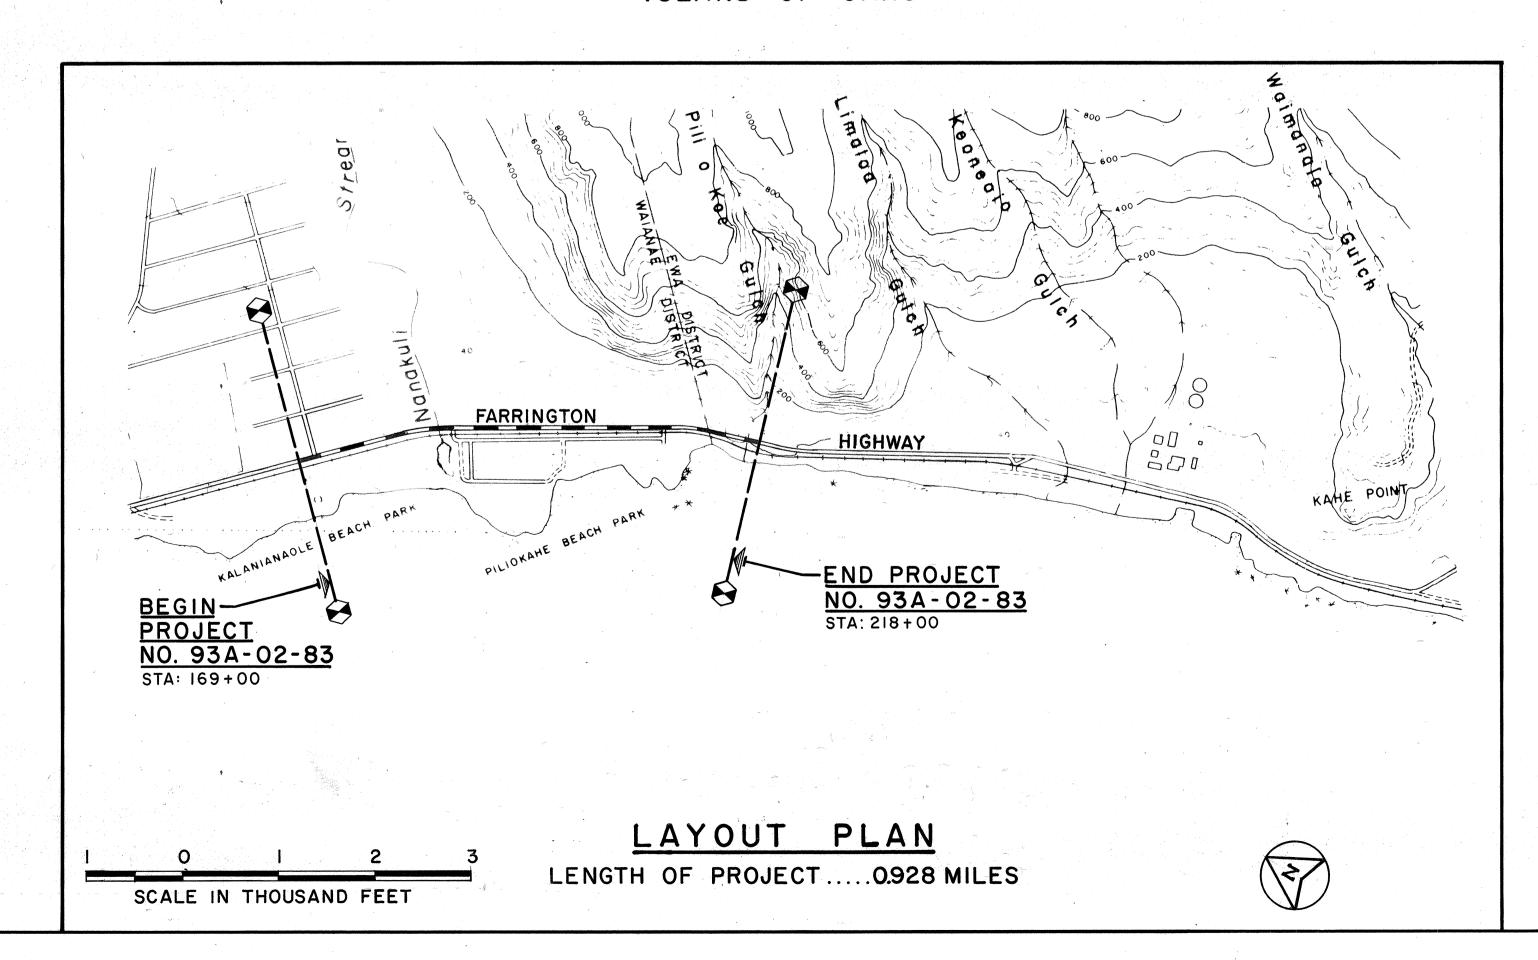

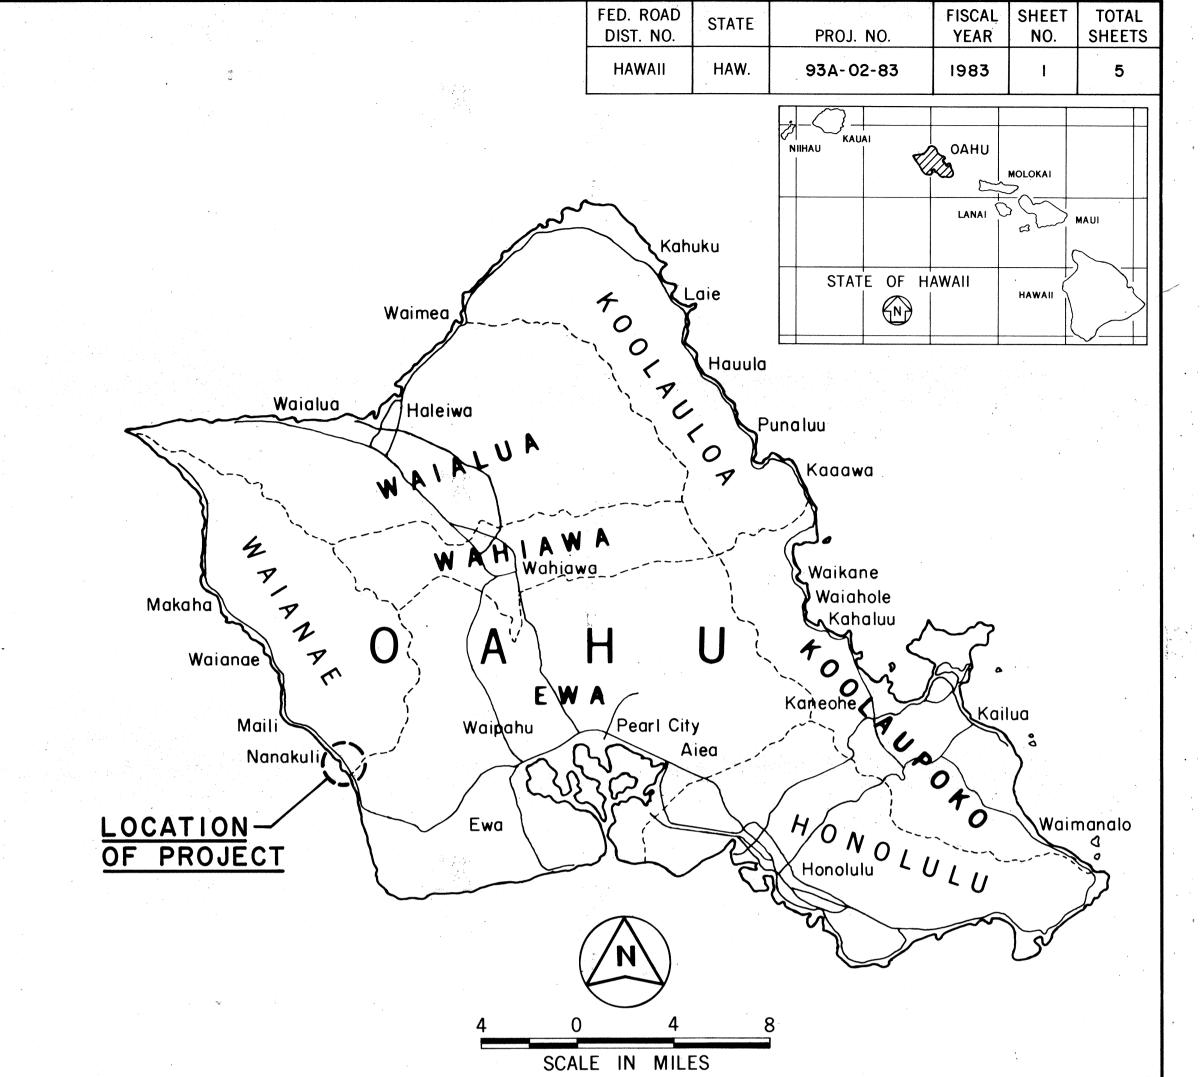

WORK COMPLETED BY HWY-OM MAY 10, 1983

ALL CHANGES MADE DURING CONSTRUCTION HAVE BEEN INCORPORATED ON THESE PLAN IN RED EXCEPT CHANGES IN THE ORIGINAL THEORETICAL QUANTITIES. FOR ACTUAL QUANTITIES, REFER TO PROJECT LEDGER AND/OR COMPUTATION BOOK.

Howard H.W.Mcan
RESIDENT ENGINEER

120/83 DATE

DEPARTMENT OF TRANSPORTATION
STATE OF HAWAII
APPROVED:

DIR. OF TRANSPORTATION DATE

D-8-10

548-4042 PHONE

FRED ABESHIMA
P. S. & E. BY

B OKITA, INC. DESIGNED BY