SHEET NO. 1 T 2 H L	EX TO DRAWINGS DESCRIPTION
1 T 2 H L	DESCRIPTION
2 H L	
3 M	TITLE SHEET
3 M	IGHWAY LIGHTING PLAN, SINGLE INE DIAGRAM AND SYMBOLS
	ISCELLANEOUS DETAILS
	ISCELLANEOUS DETAILS
. 5 M	ISCELLANEOUS DETAILS
30	
	, .





DEPARTMENT OF TRANSPORTATION LAND TRANSPORTATION FACILITIES DIVISION HONOLULU, HAWAII

PLANS FOR


KAMEHAMEHA HIGHWAY,


POAMOHO BRIDGE LIGHTS

PROJECT NO. 99A-OI-76

DISTRICT OF WAHIAWA & WAIALUA

ISLAND OF OAHU

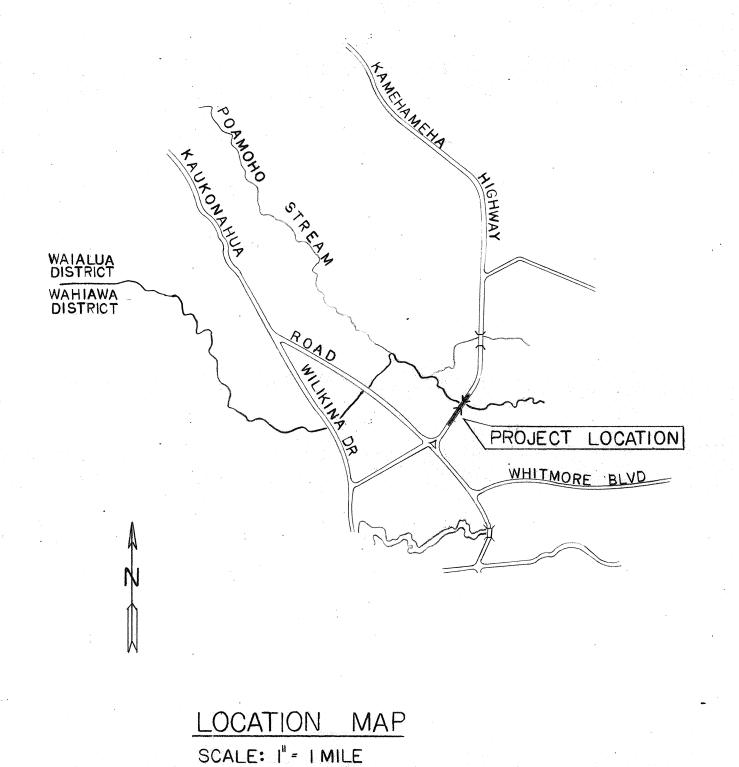

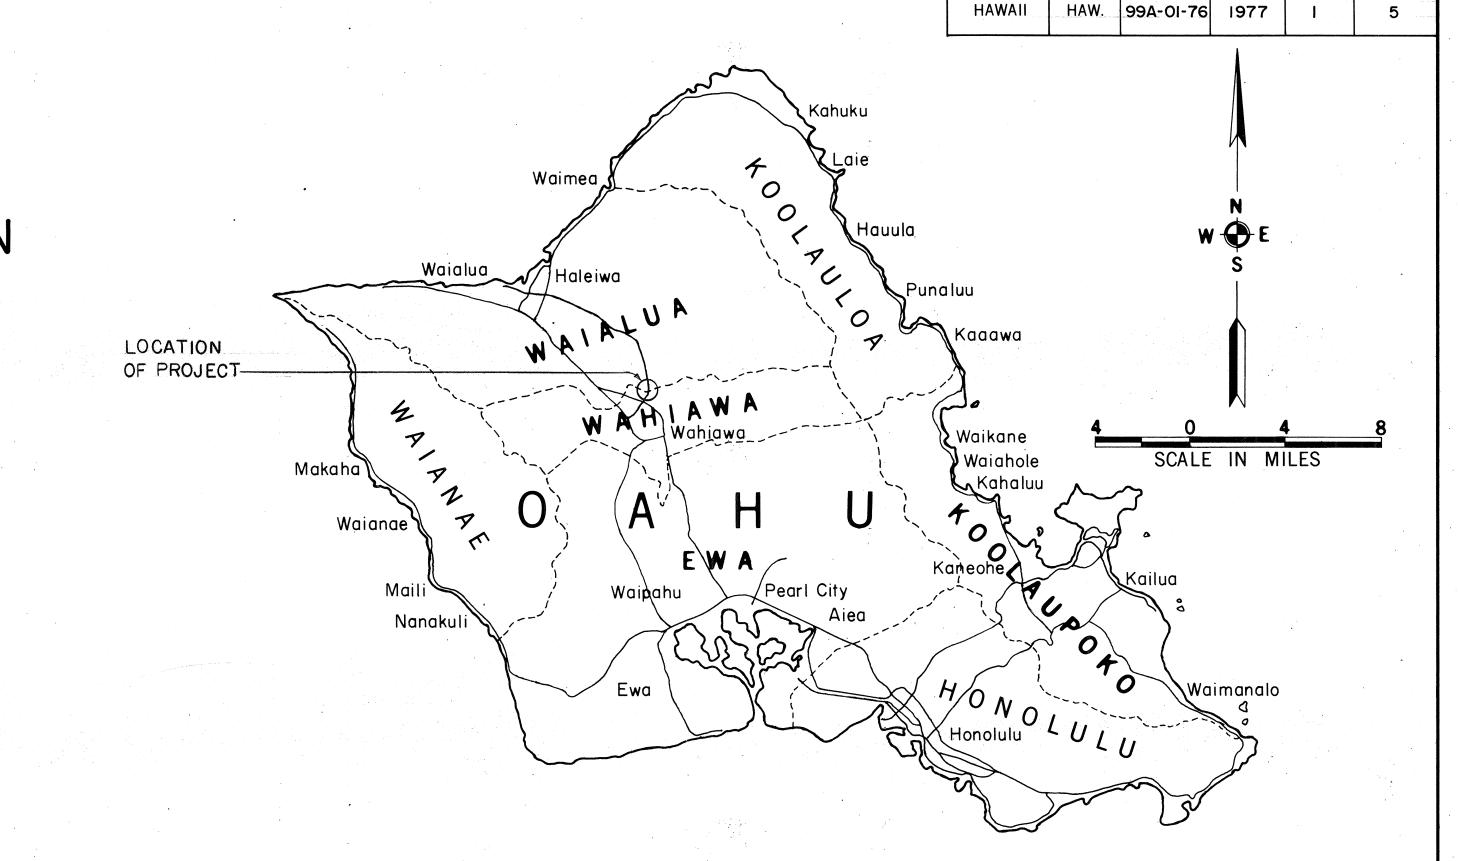

NO AS-BUILT CHANGES MADE DURING CONSTRUCTION.

Garaf & Mola

RESIDENT ENGINEER

DATE

DEPARTMENT OF TRANSPORTATION
STATE OF HAWAII

APPROVED:

Regashionna 1/3/77

DIR. OF TRANSPORTATION DATE

HONG ASSO., INC.

J. SUGIHARA
548-6932
8-29-77
IGNED BY
P. S. & E. BY
PHONE
DATE

1-8-0-00

П

9/16/77 DATE

10.35-77 DATE

HAWAIIAN TELEPHONE COMPANY

FISCAL YEAR