


FED. ROAD DIST. NO.	STATE	FED. AID PROJ. NO.	FISCAL YEAR	SHEET NO.	TOTAL SHEETS
HAWAII	HAW.	I-HI-1(102)8	1973	5	38

LEGEND
 --- SCU SIGNAL CORPS CABLE
 --- HTC HAW TEL CABLE
 --- HE HECO CABLE

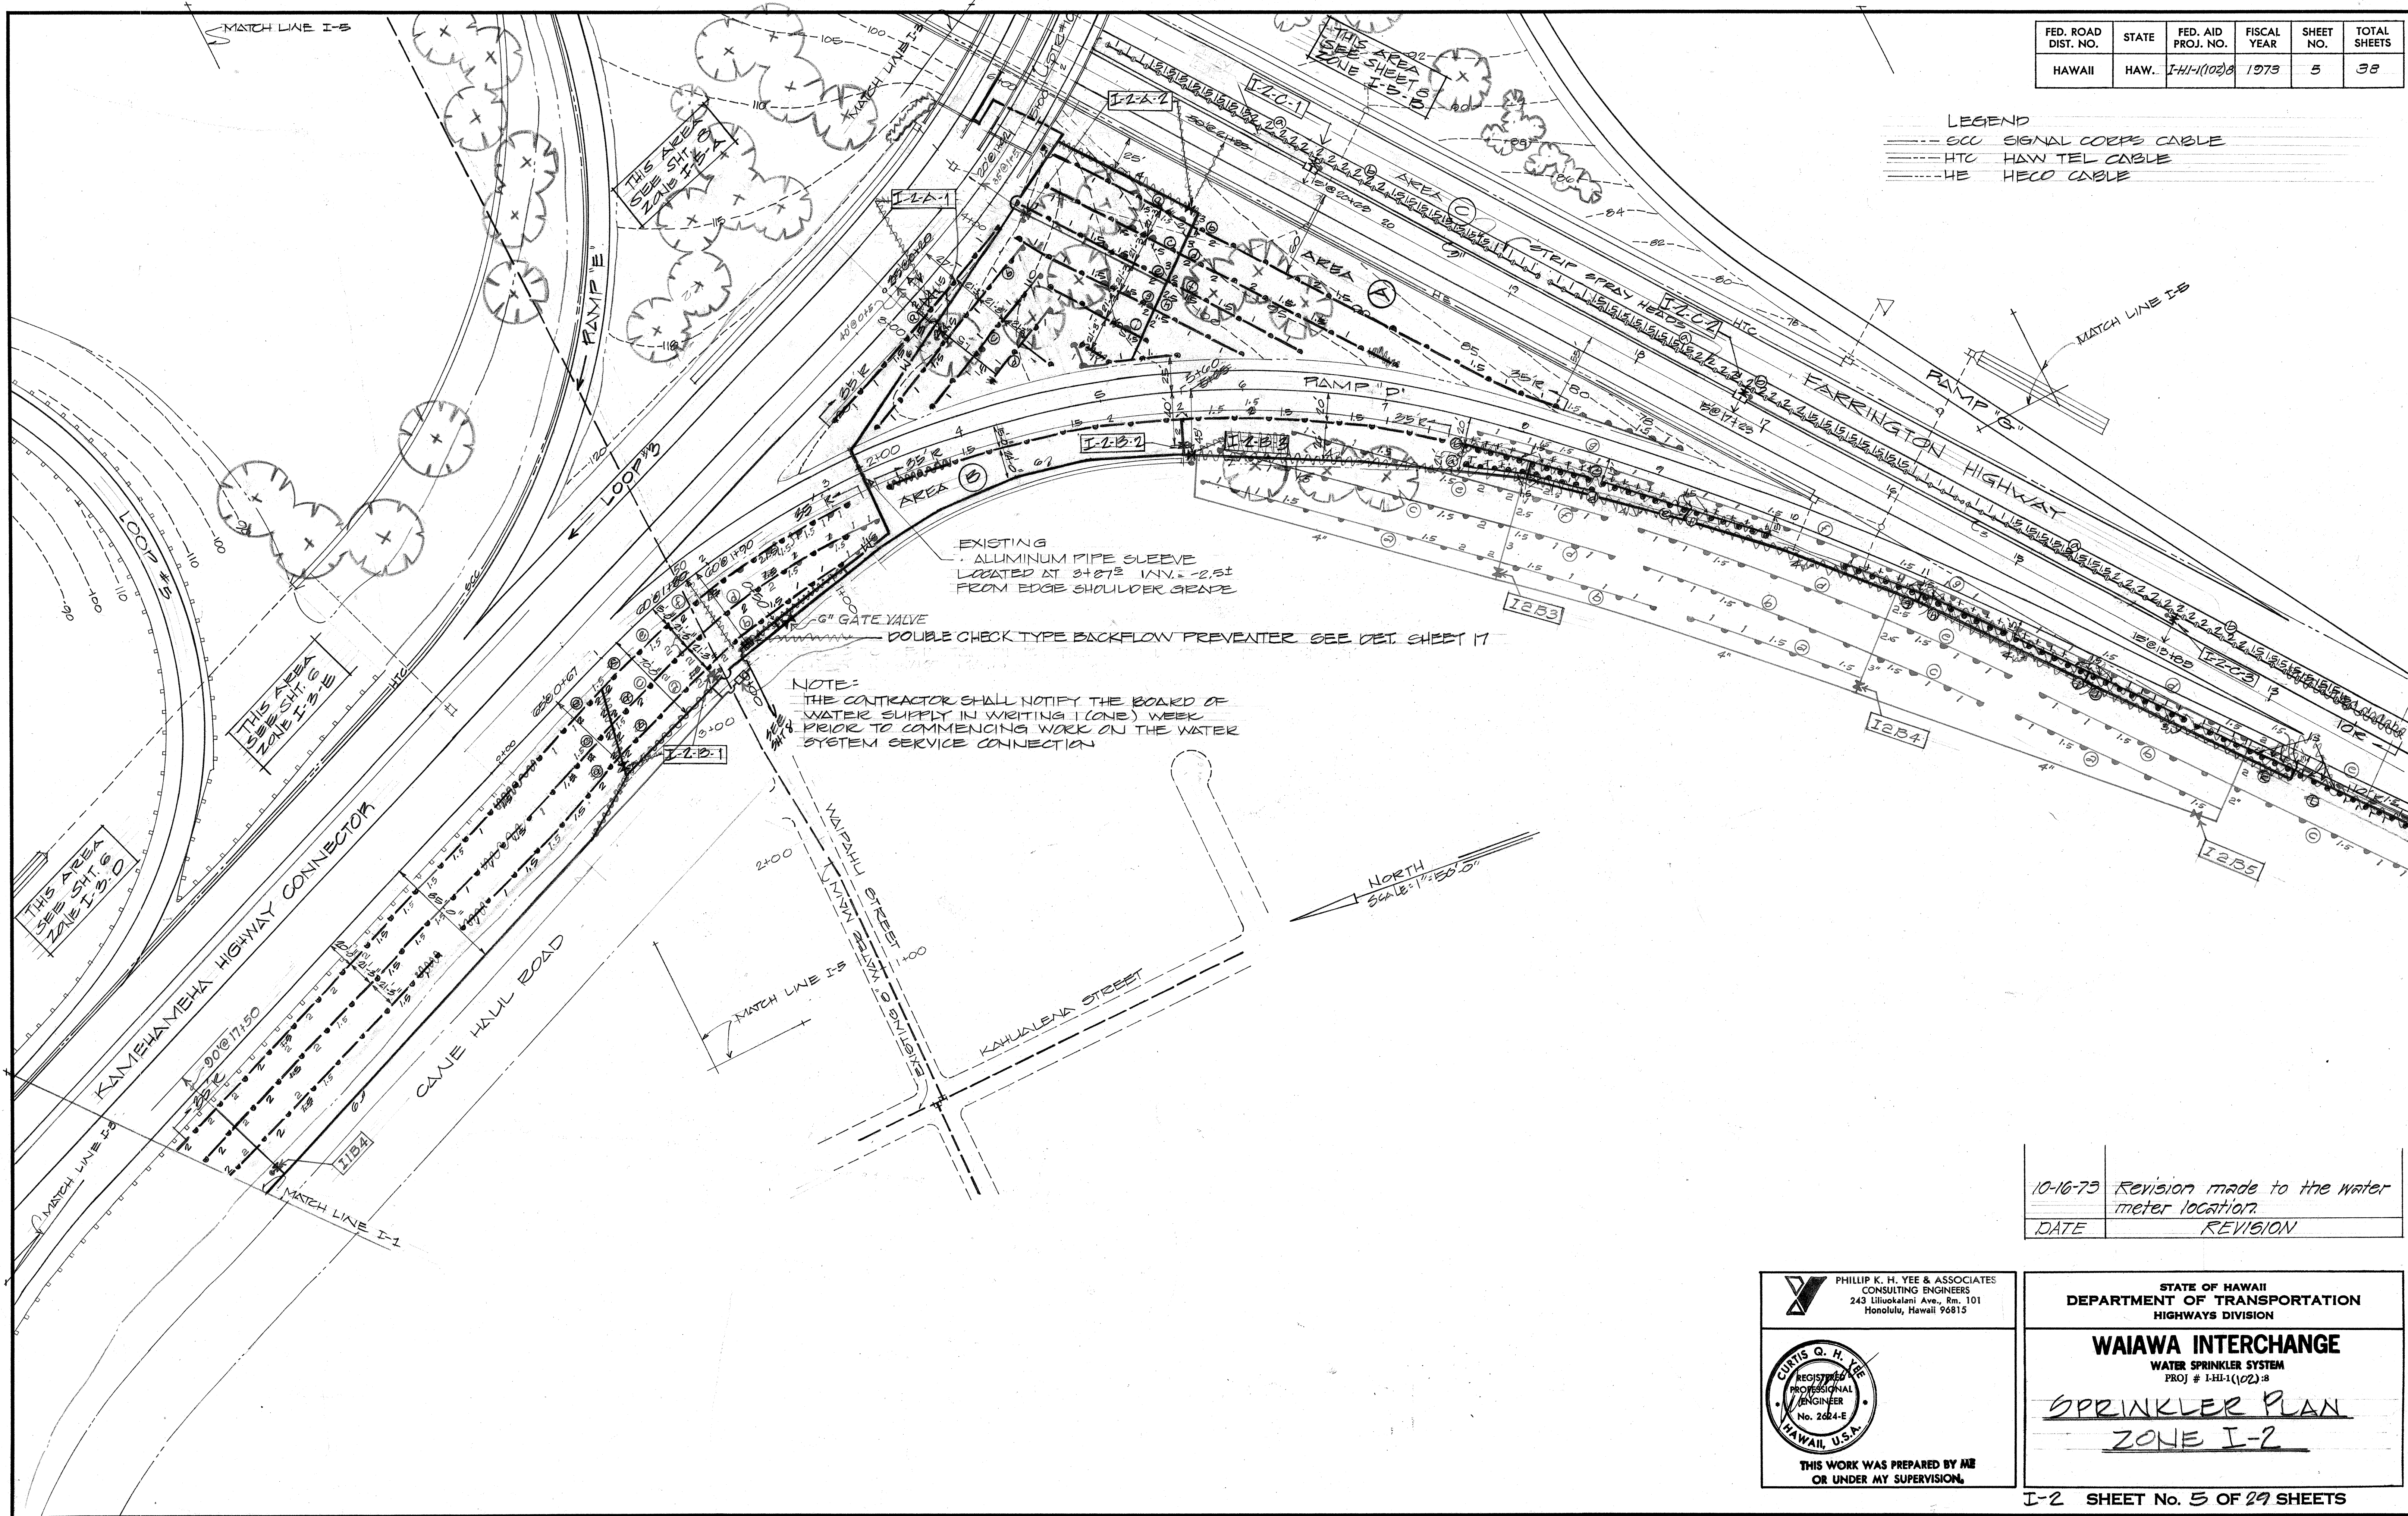

10-10-73	Revision made to the water meter location.
DATE	REVISION

PHILLIP K. H. YEE & ASSOCIATES
 CONSULTING ENGINEERS
 243 Liliuokalani Ave., Rm. 101
 Honolulu, Hawaii 96815

CURTIS Q. H. YEE
 REGISTERED PROFESSIONAL ENGINEER
 No. 2024-E
 HAWAII, U.S.A.

THIS WORK WAS PREPARED BY ME
 OR UNDER MY SUPERVISION.


STATE OF HAWAII
 DEPARTMENT OF TRANSPORTATION
 HIGHWAYS DIVISION

WAIAWA INTERCHANGE
 WATER SPRINKLER SYSTEM
 PROJ # I-HI-1(102)8

SPRINKLER PLAN
 ZONE I-2

I-2 SHEET No. 5 OF 29 SHEETS

FED. ROAD DIST. NO.	STATE	FED. AID PROJ. NO.	FISCAL YEAR	SHEET NO.	TOTAL SHEETS
HAWAII	HAW.	I-HI-1(102)B	1973	6	38

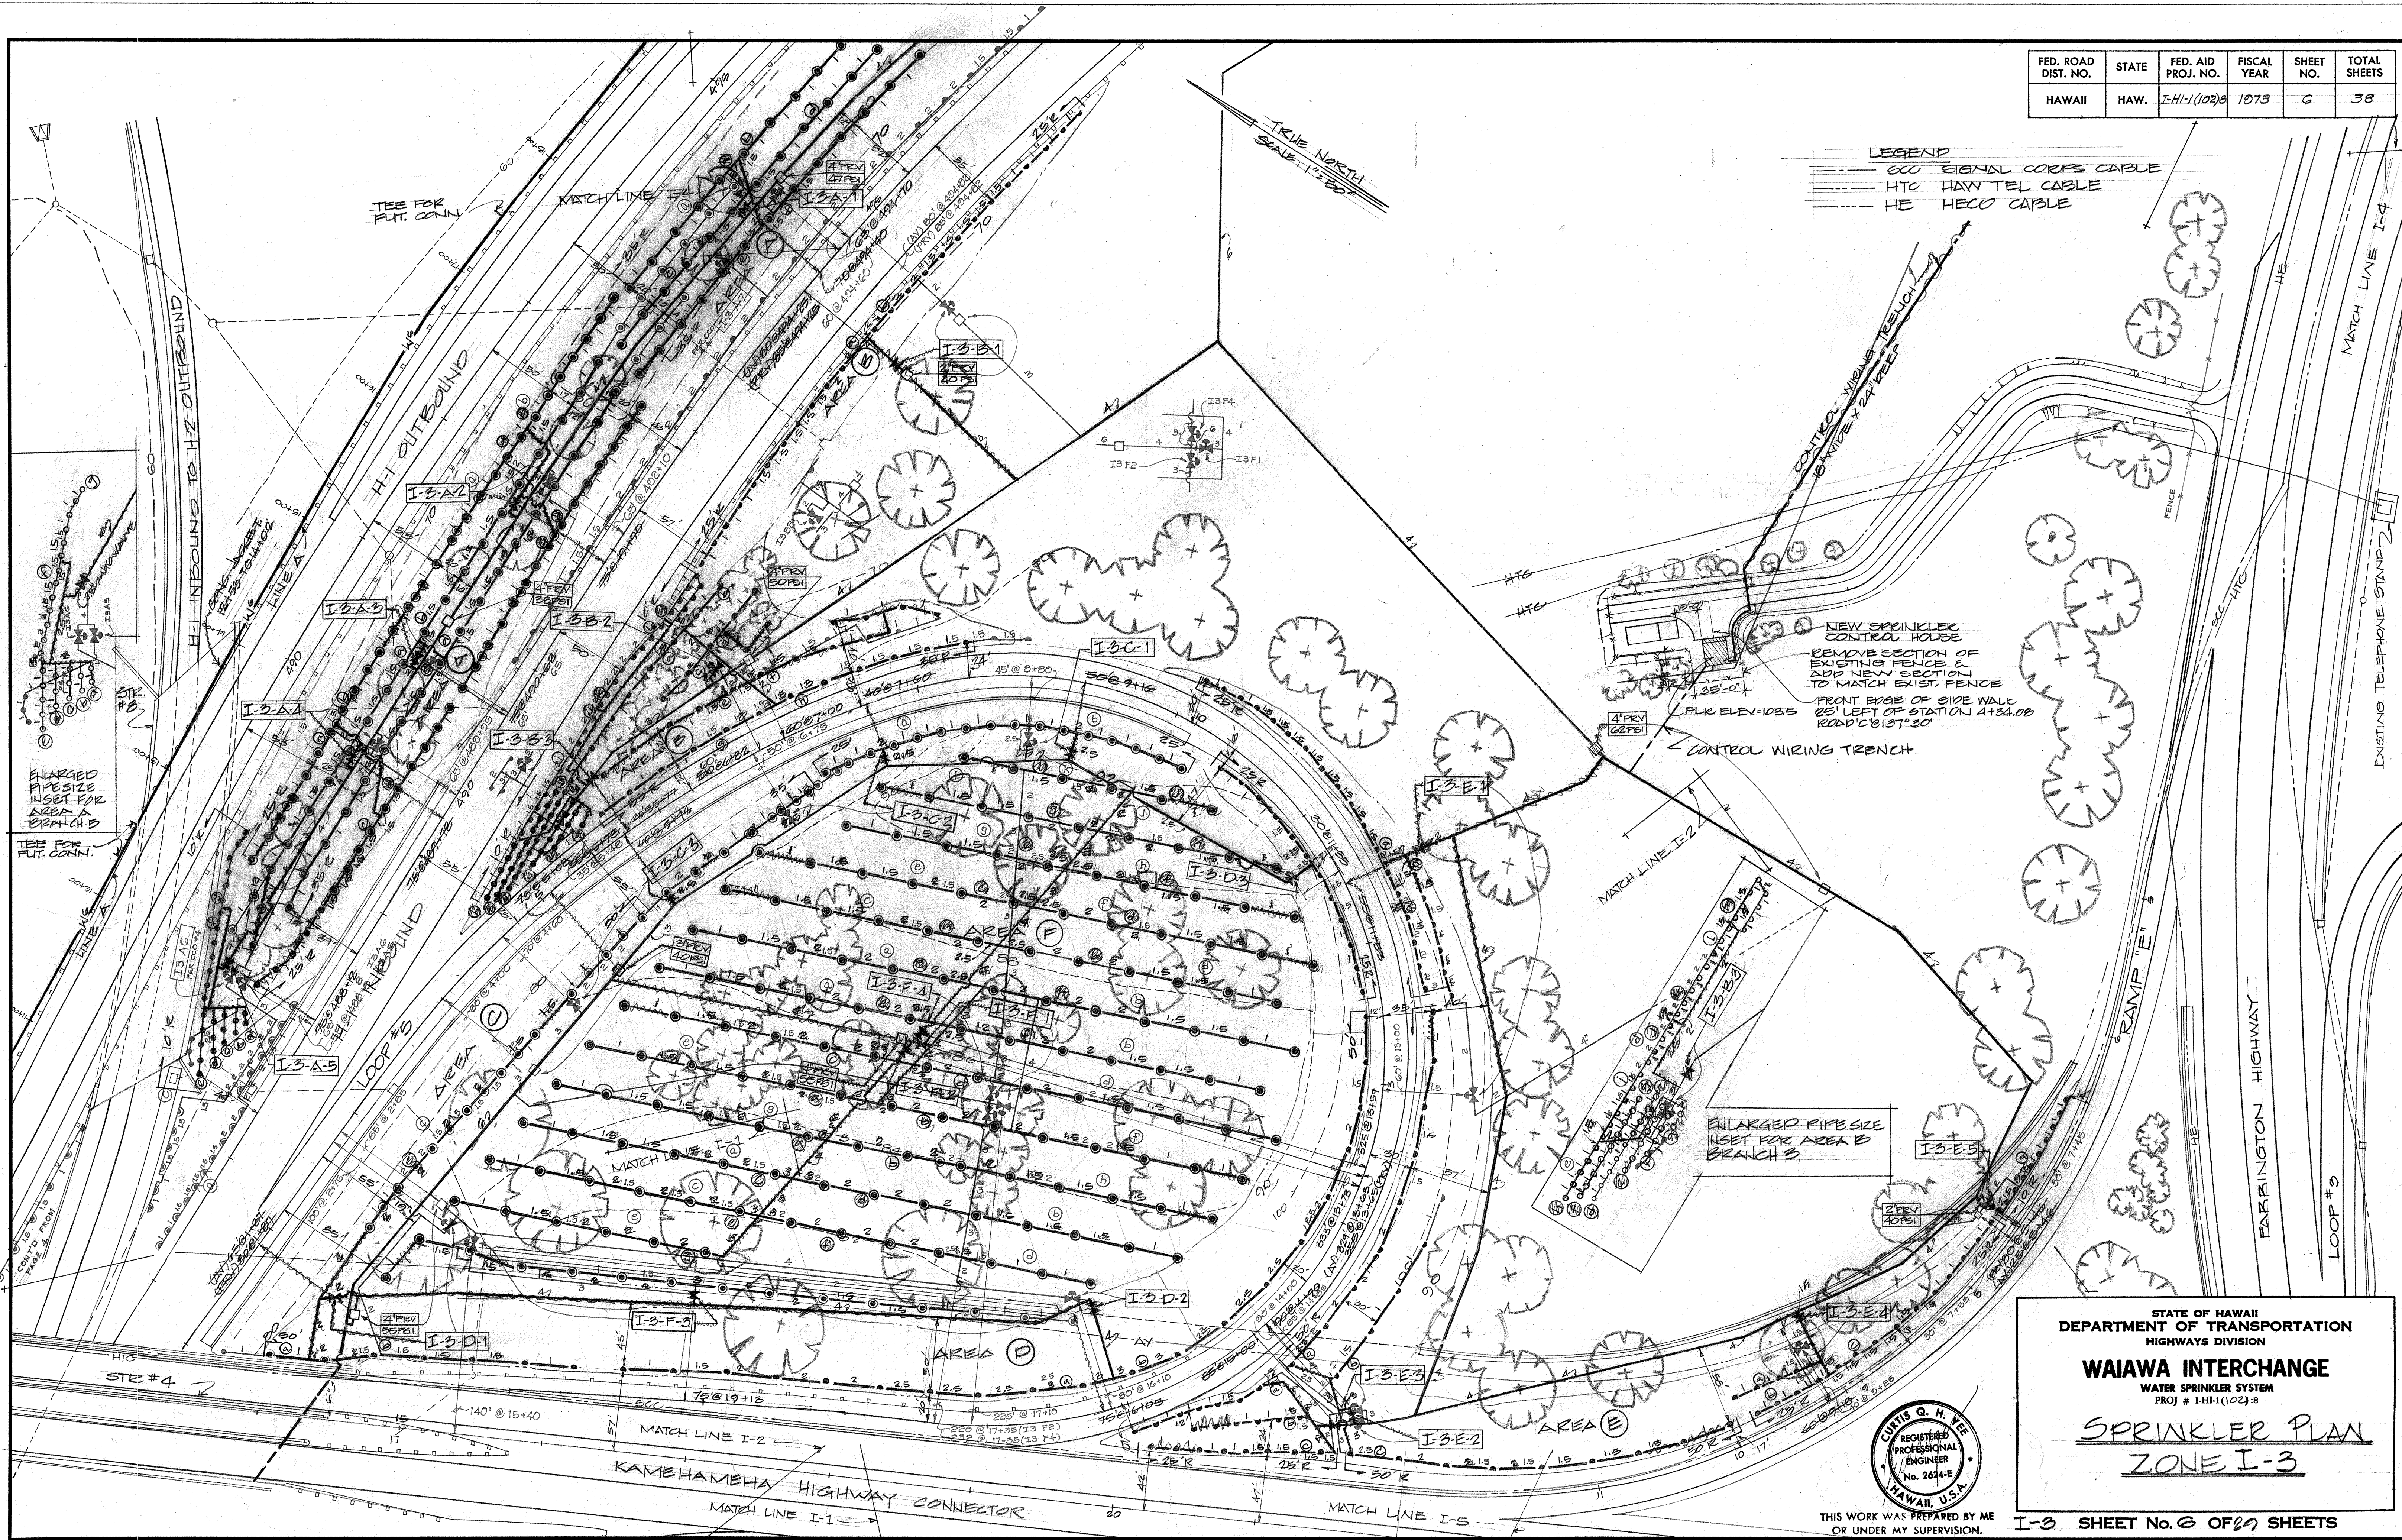

ORIGINAL PLAN	SURVEY PLOTTED BY _____	DATE _____
NOTE BOOK	DRAWN BY _____	_____
	TRACED BY _____	_____
	DESIGNED BY _____	_____
	QUANTITIES BY _____	_____
No. _____	CHECKED BY _____	_____

STATE OF HAWAII
DEPARTMENT OF TRANSPORTATION
HIGHWAYS DIVISION

WAIAWA INTERCHANGE


WATER SPRINKLER SYSTEM
PROJ # 1-HI-11(102) :8

SPRINKLER PLAN
ZONE I-3

I-3 SHEET No. 6 OF 29 SHEETS


FED. ROAD DIST. NO.	STATE	FED. AID PROJ. NO.	FISCAL YEAR	SHEET NO.	TOTAL SHEETS
HAWAII	HAW.	I-H-1(102)8	1973	7	38

ORIGINAL PLAN	DATE
DRAWN BY	
DESIGNED BY	
QUANTITIES BY	
CHECKED BY	

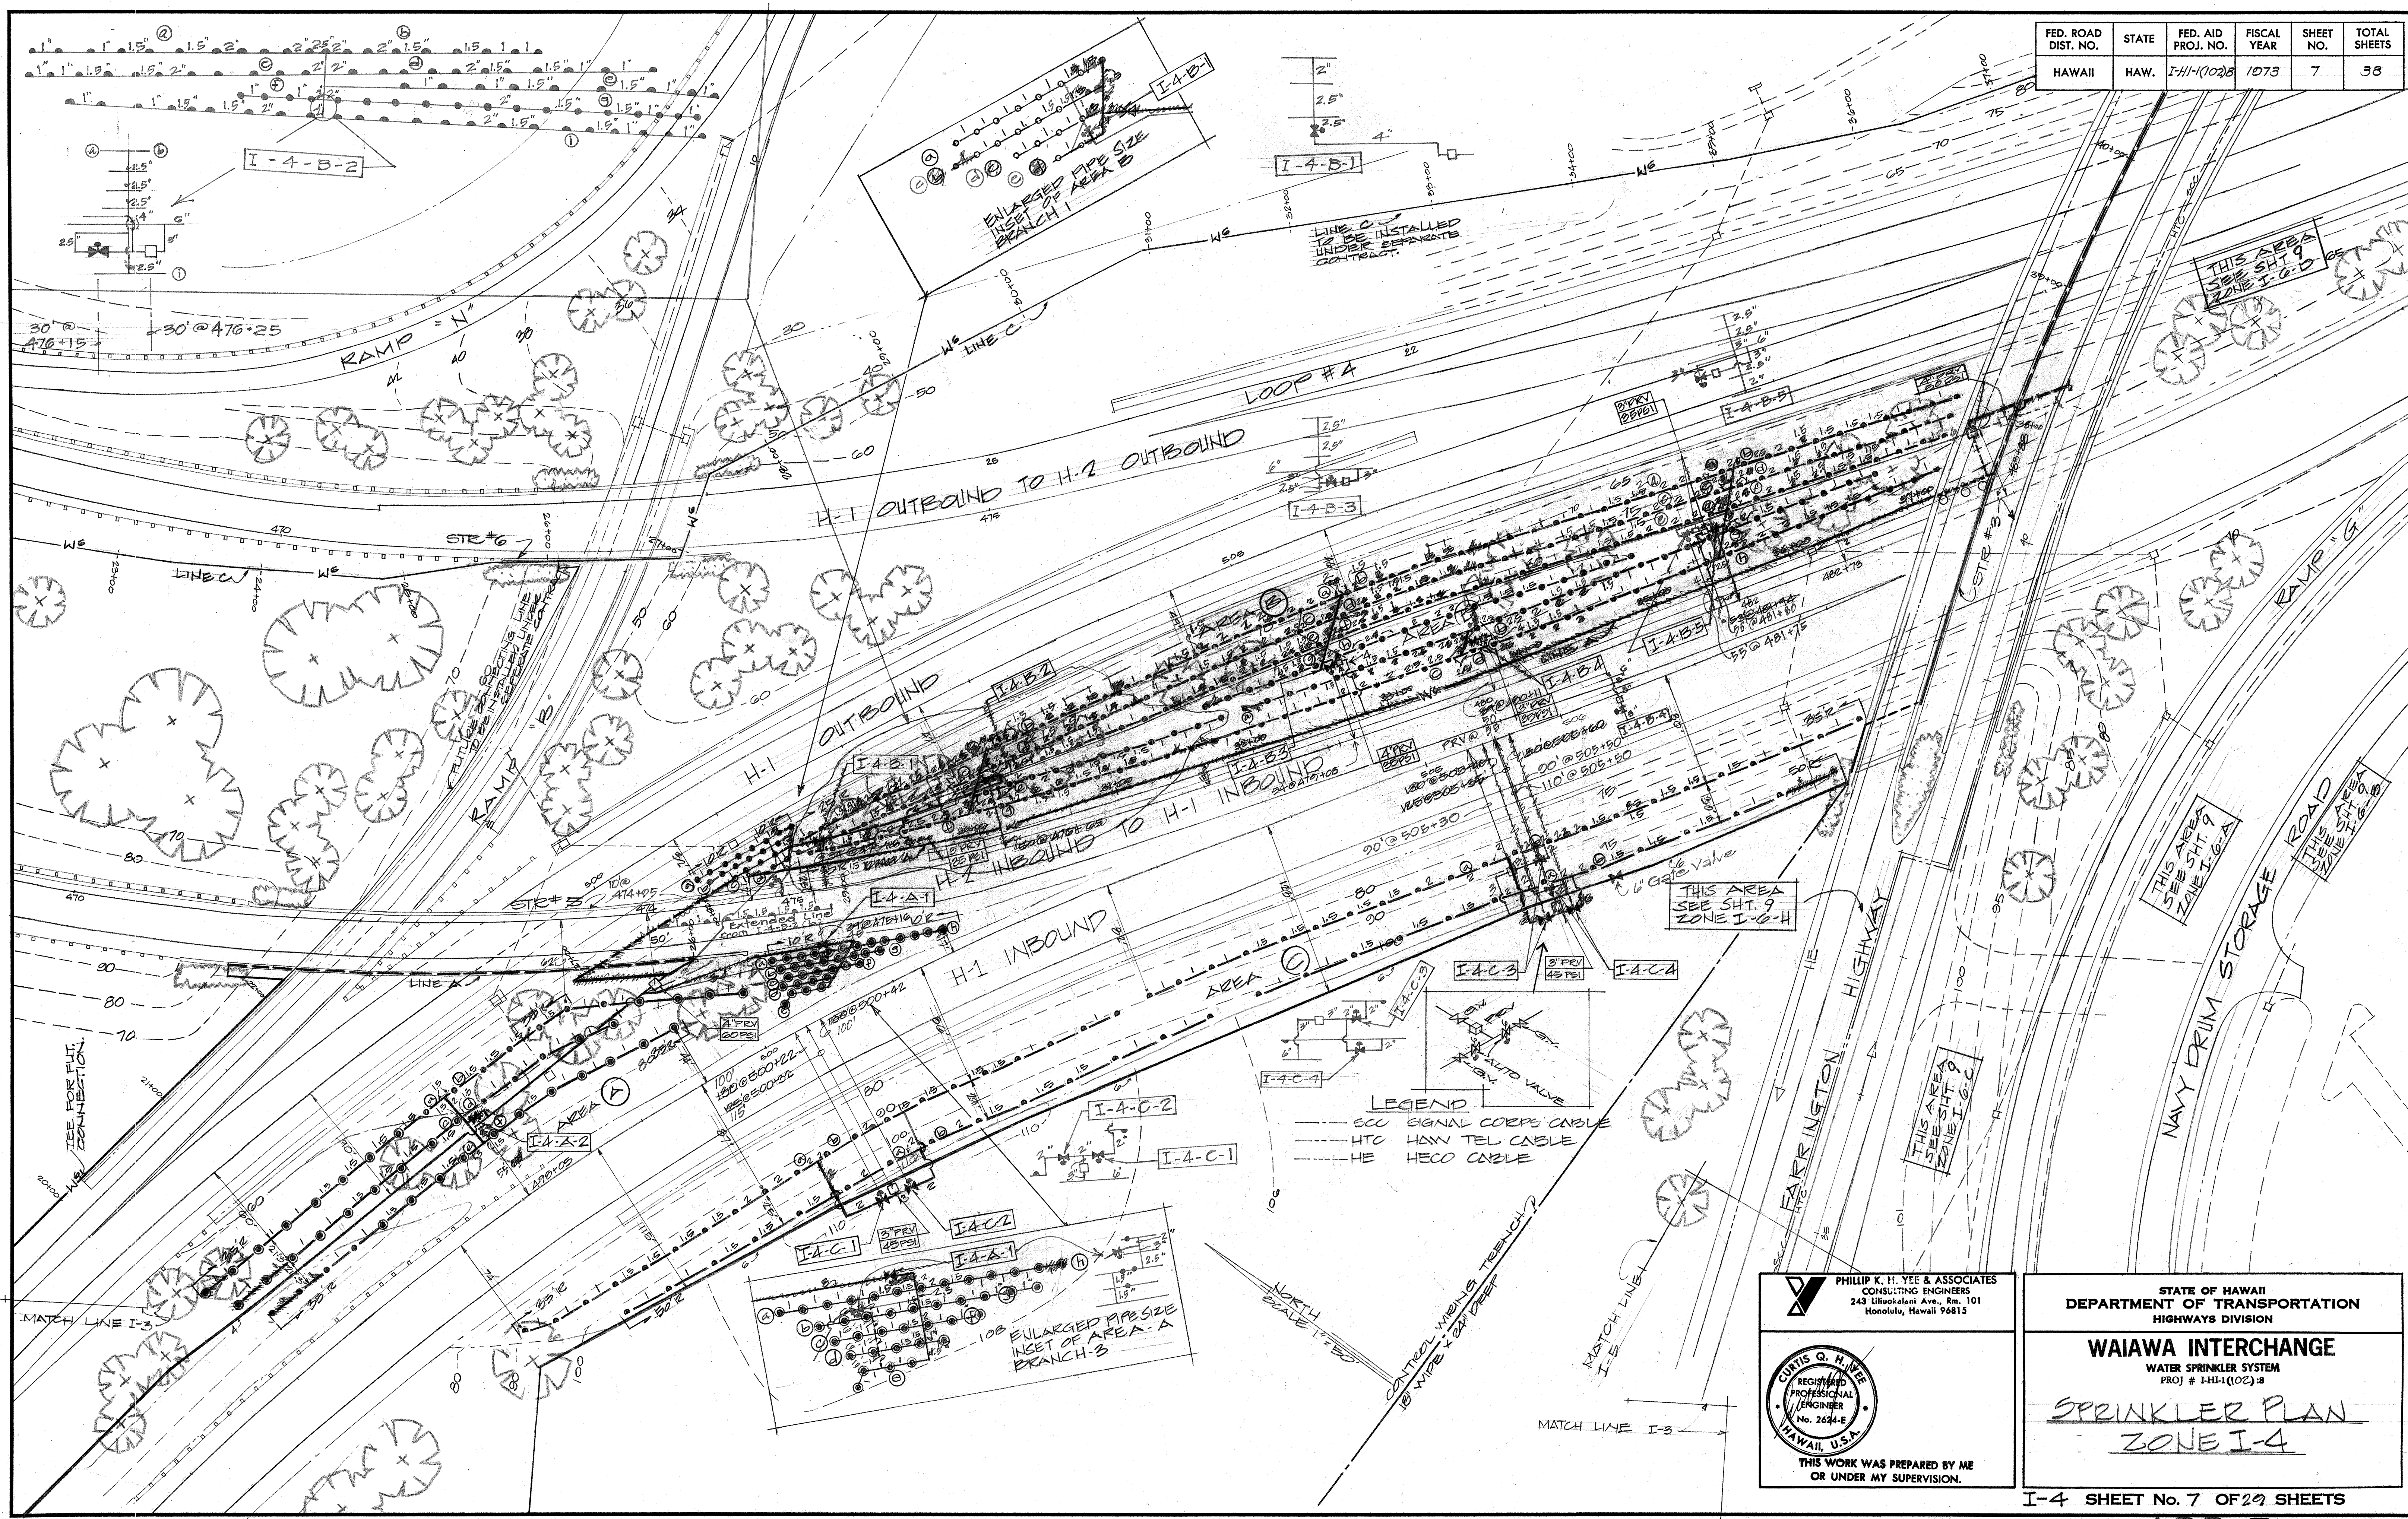



PHILLIP K. H. YEE & ASSOCIATES
 CONSULTING ENGINEERS
 243 Liliuokalani Ave., Rm. 101
 Honolulu, Hawaii 96815

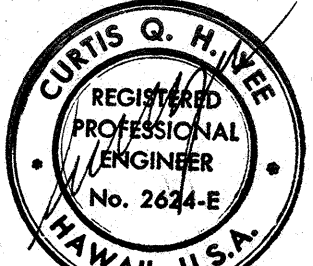

THIS WORK WAS PREPARED BY ME
 OR UNDER MY SUPERVISION.

STATE OF HAWAII
 DEPARTMENT OF TRANSPORTATION
 HIGHWAYS DIVISION



WAIAWA INTERCHANGE
 WATER SPRINKLER SYSTEM
 PROJ # I-H-1(102)8

SPRINKLER PLAN
ZONE I-4

I-4 SHEET No. 7 OF 38 SHEETS

ADD. 7

FED. ROAD DIST. NO.	STATE	FED. AID PROJ. NO.	FISCAL YEAR	SHEET NO.	TOTAL SHEETS
HAWAII	HAW.	I-H-1(102)3	1973	9	36

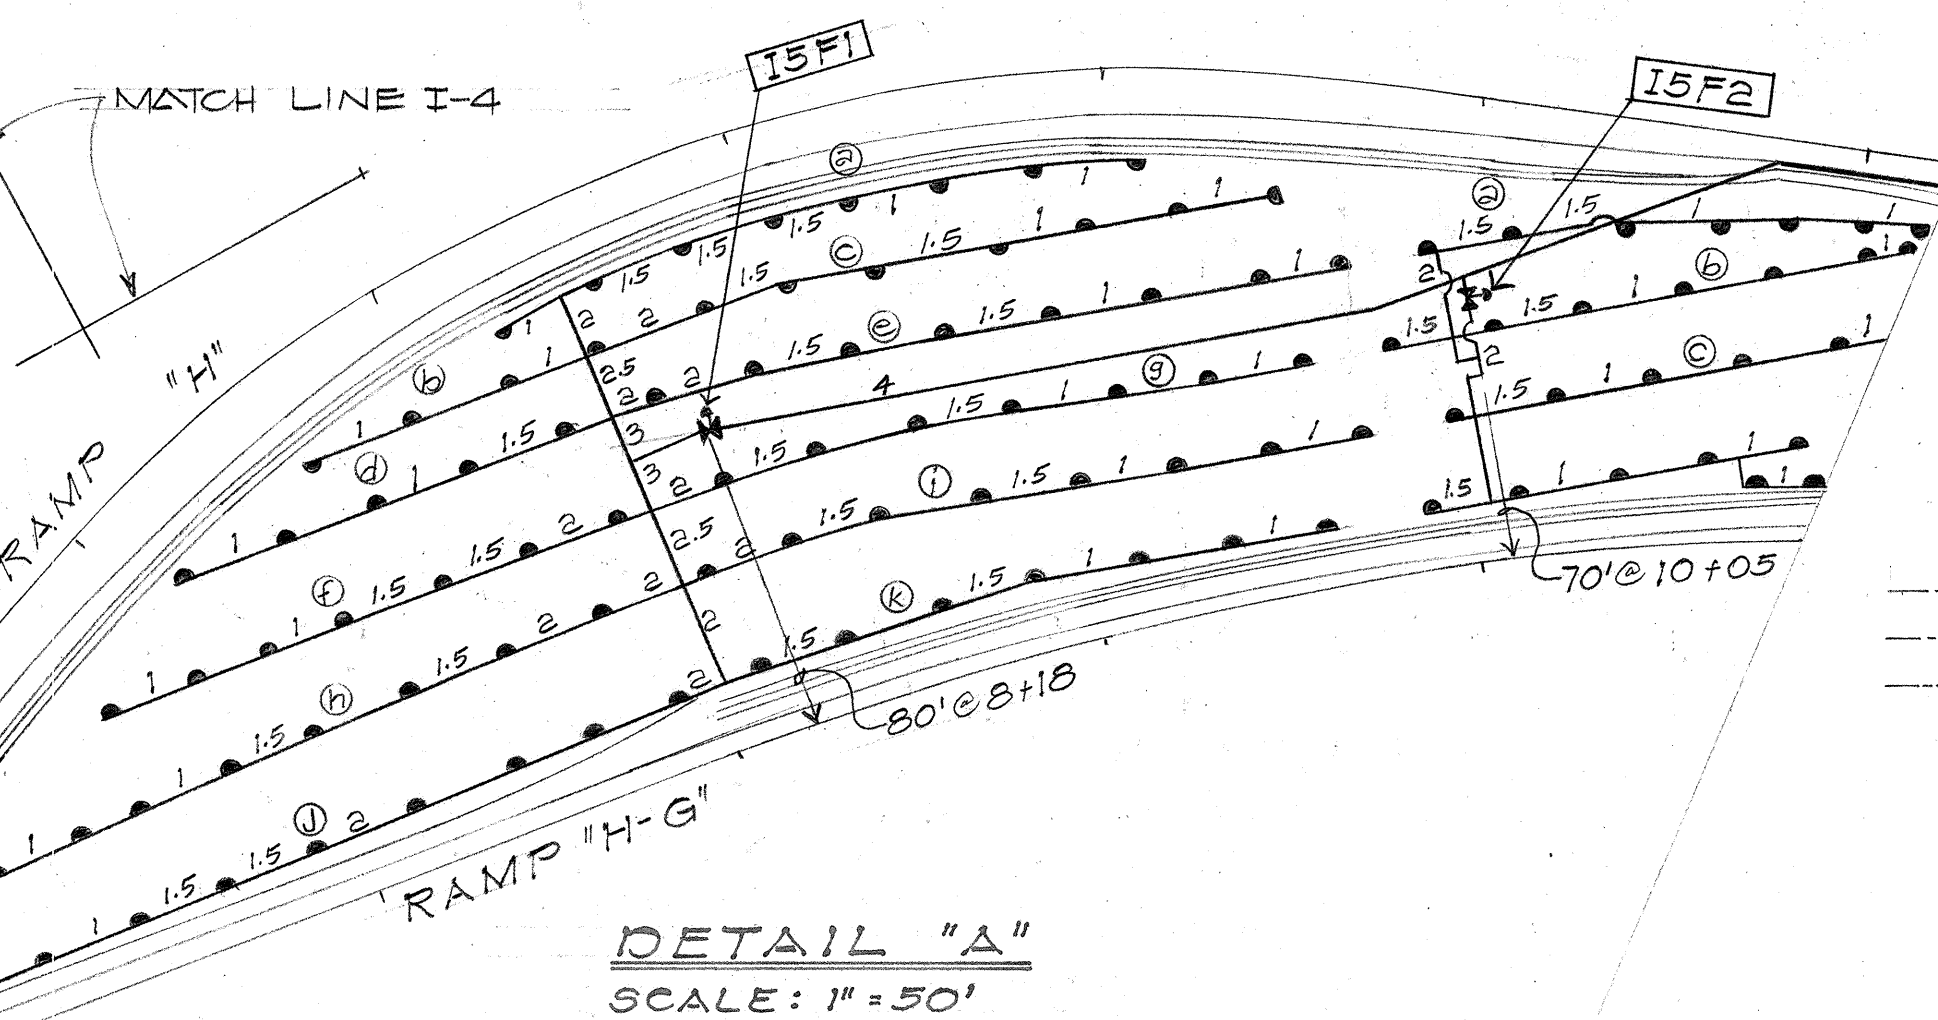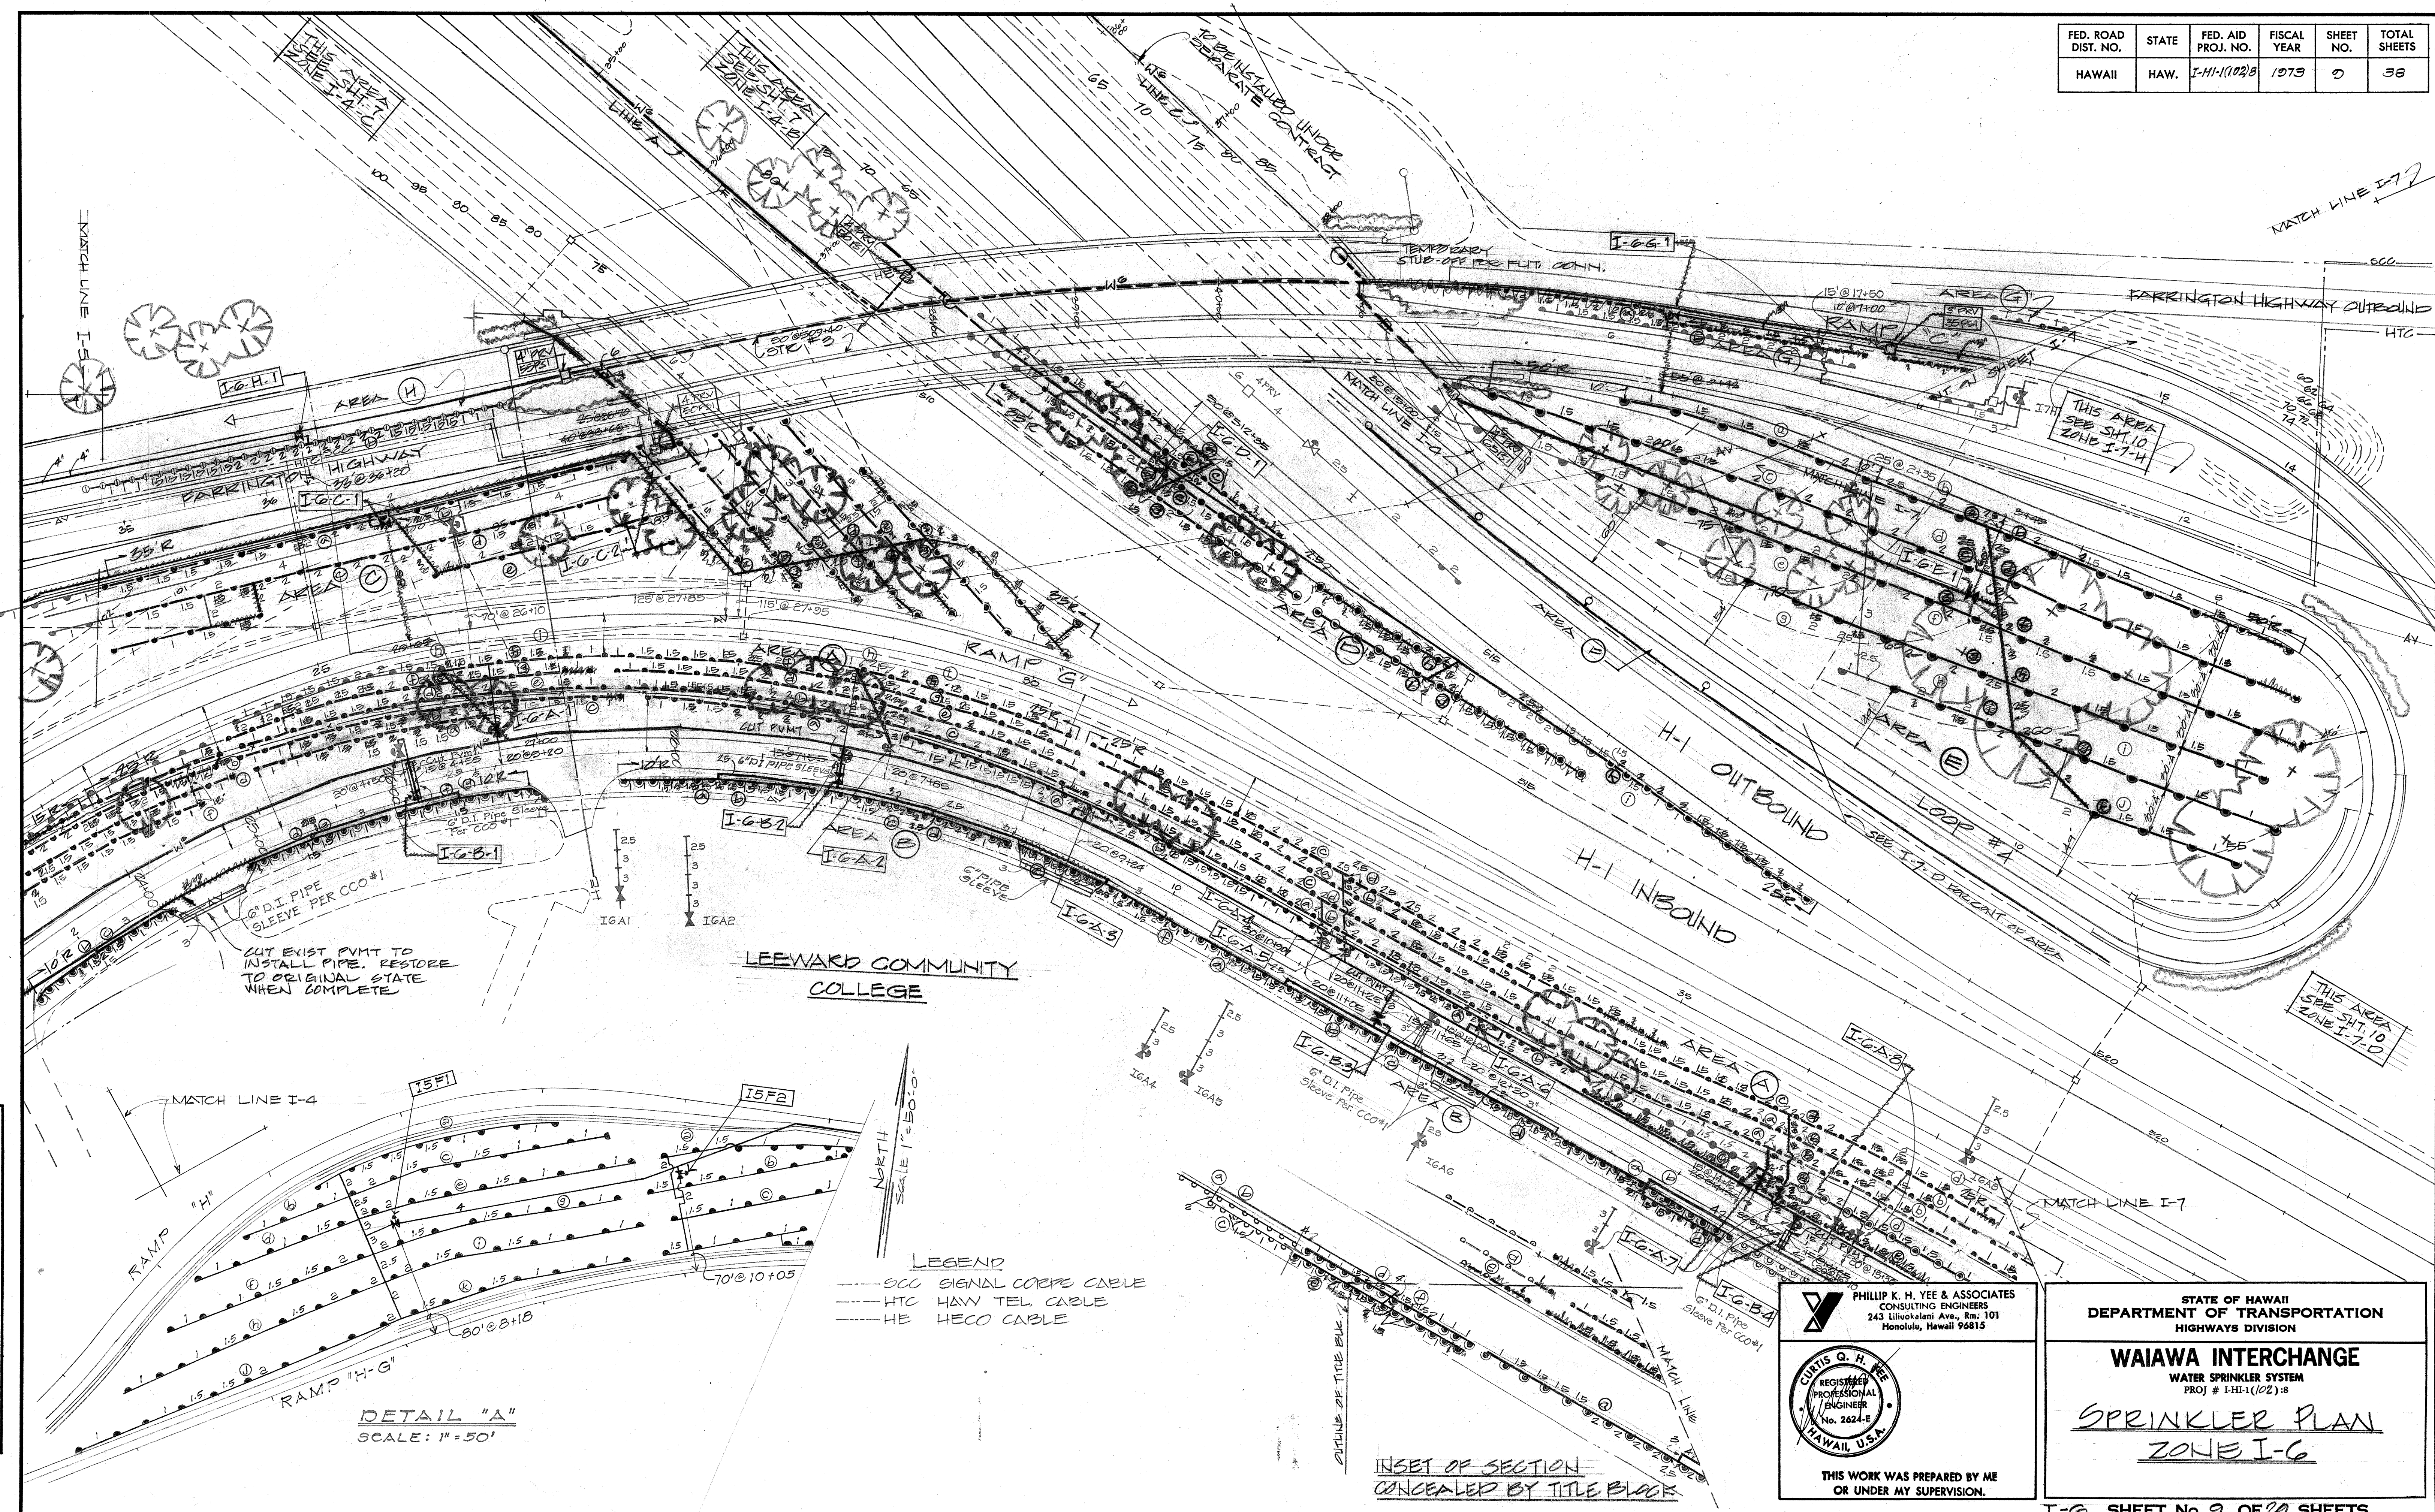

- LEGEND
- OCC SIGNAL CORPS CABLE
 - HTC HAV TEL CABLE
 - HE HECO CABLE

INSET OF SECTION CONCEALED BY TITLE BLOCK

DATE	_____
SURVEY PLOTTED BY	_____
DESIGNED BY	_____
NOTED BY	_____
CHECKED BY	_____
ORIGINAL PLAN	_____
NOTE BOOK	_____

PHILLIP K. H. YEE & ASSOCIATES
CONSULTING ENGINEERS
243 Liliuokalani Ave., Rm. 101
Honolulu, Hawaii 96815

CURTIS Q. H. YEE
REGISTERED PROFESSIONAL ENGINEER
No. 2624-E
HAWAII, U.S.A.


THIS WORK WAS PREPARED BY ME OR UNDER MY SUPERVISION.

STATE OF HAWAII
DEPARTMENT OF TRANSPORTATION
HIGHWAYS DIVISION

WAIAWA INTERCHANGE
WATER SPRINKLER SYSTEM
PROJ # I-H-1(102):3

SPRINKLER PLAN
ZONE I-6

FED. ROAD DIST. NO.	STATE	FED. AID PROJ. NO.	FISCAL YEAR	SHEET NO.	TOTAL SHEETS
HAWAII	HAW.	I-H-1(102)-8	1979	10	38

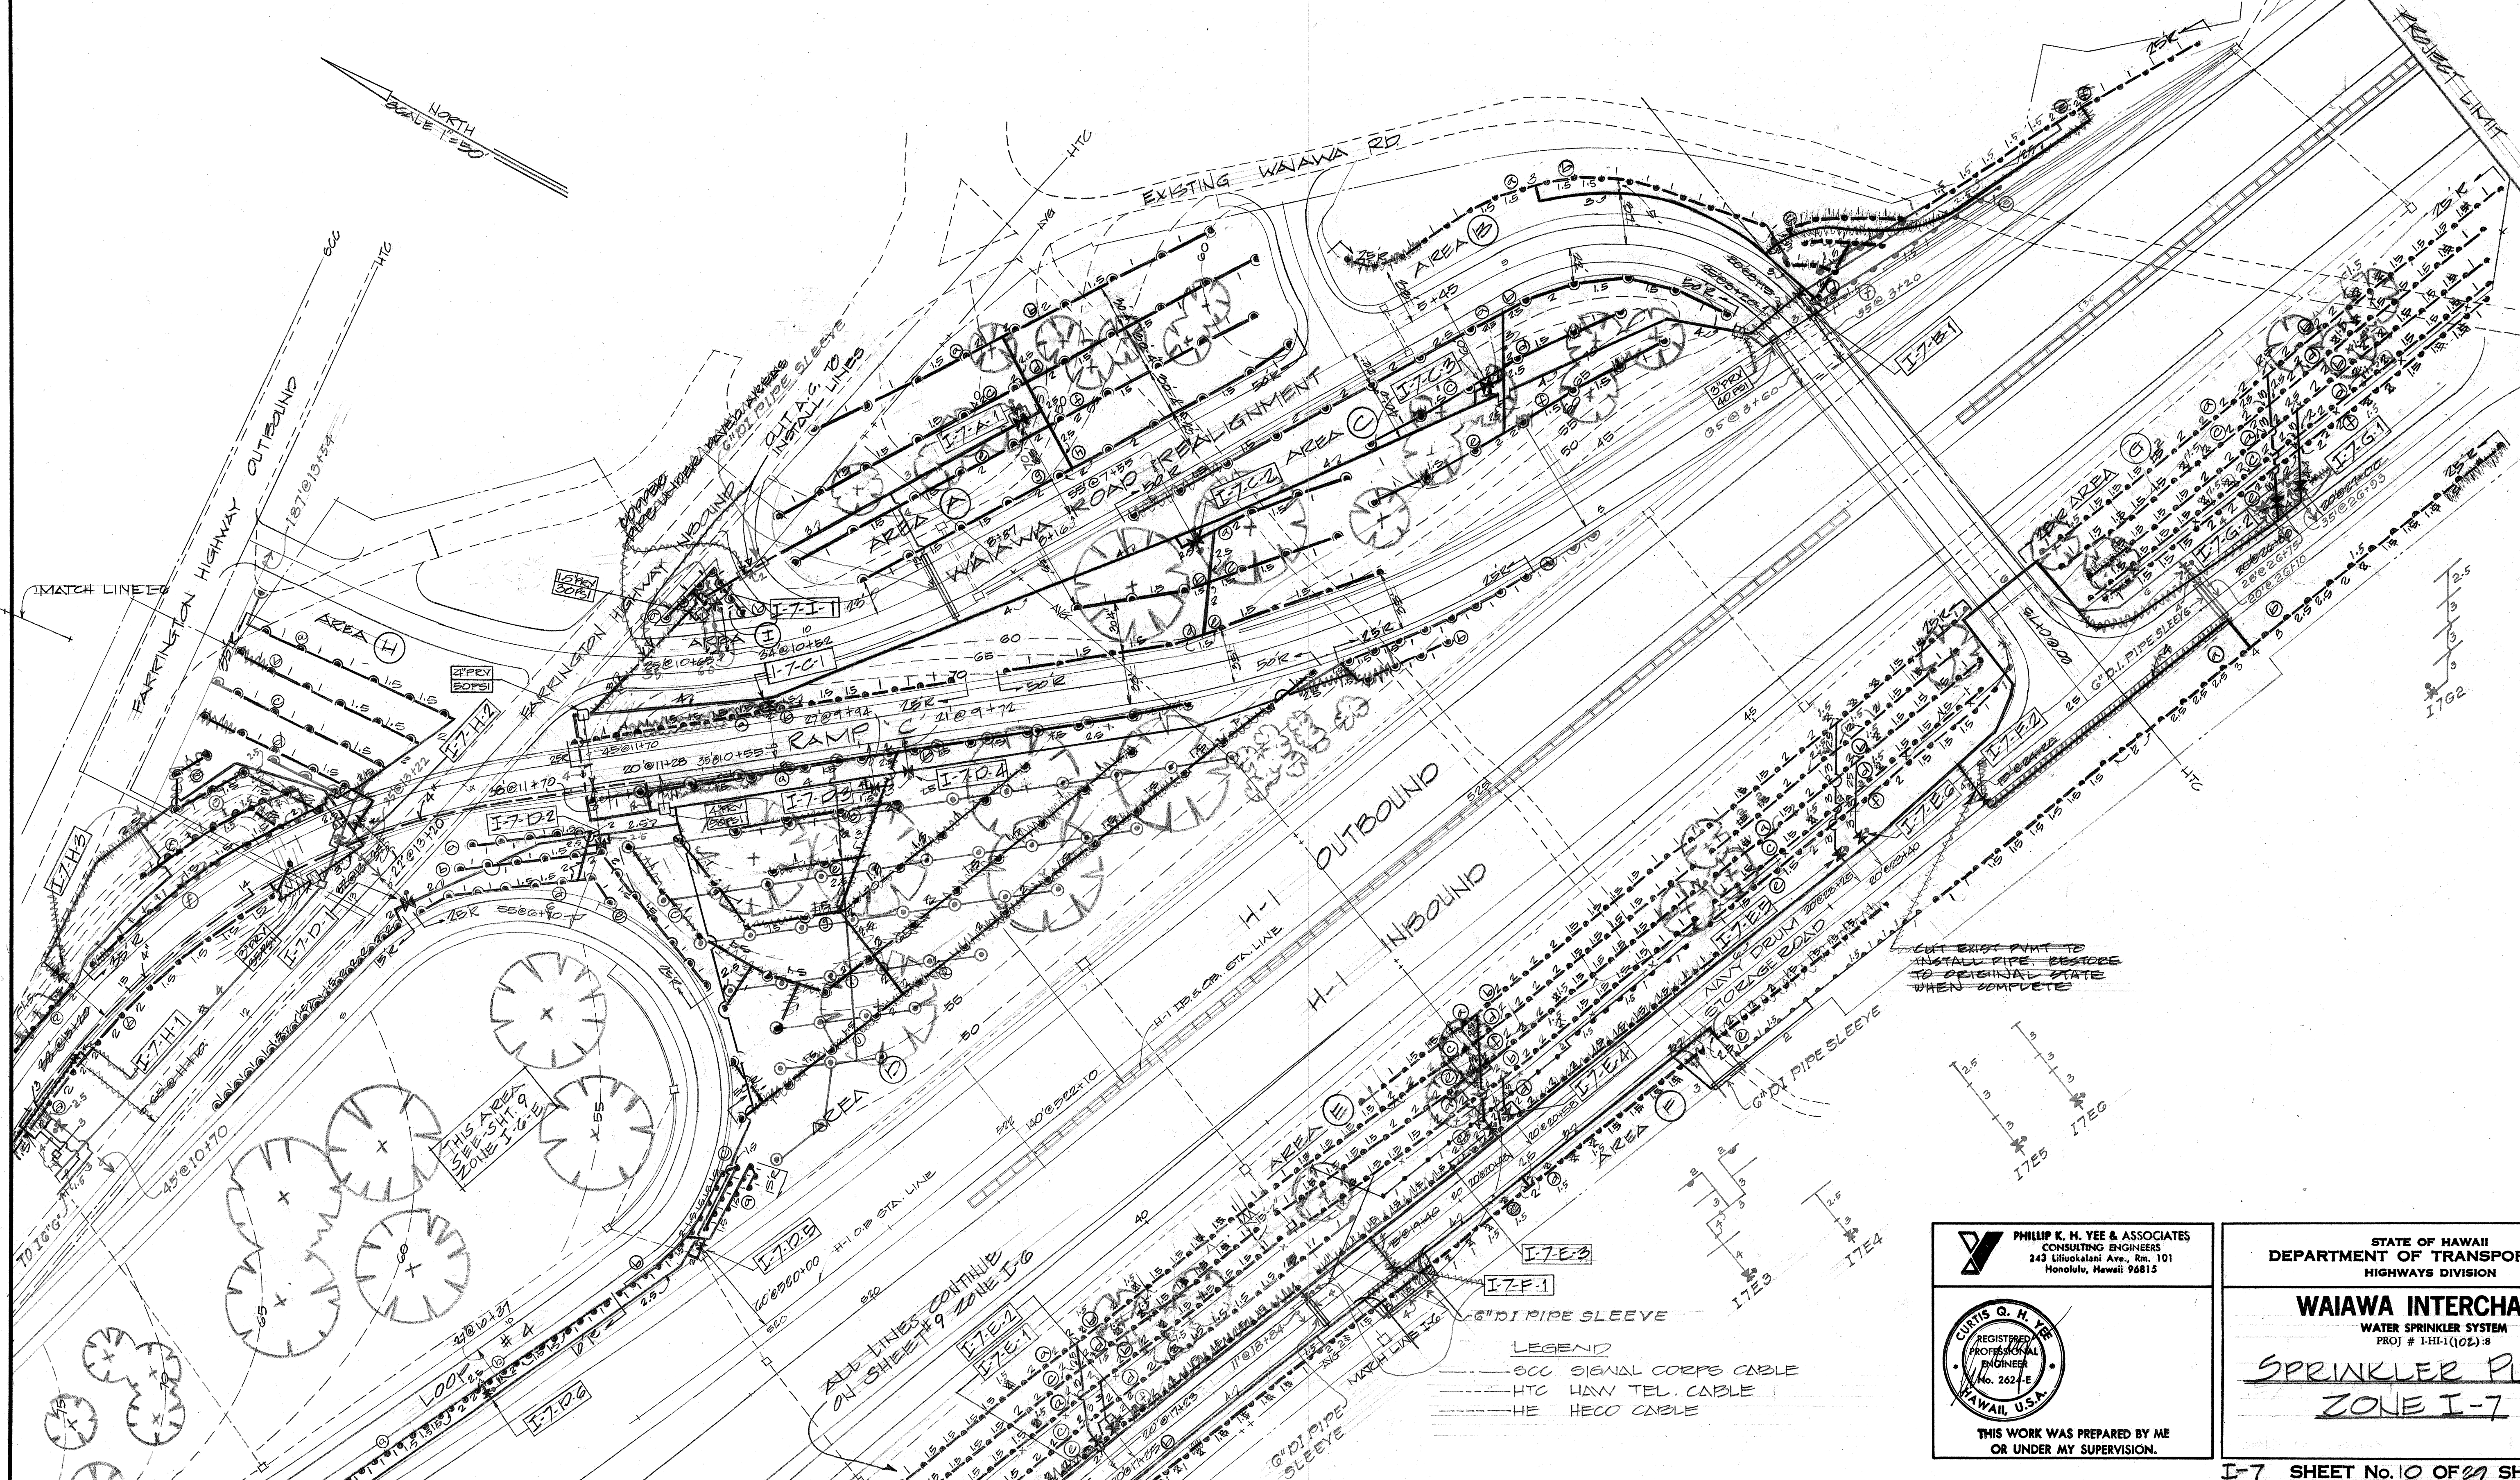

DATE	_____
DESIGNED BY	_____
TRACED BY	_____
NOTED BY	_____
CHECKED BY	_____

- LEGEND
- OCC SIGNAL CORPS CABLE
 - HTC HAW TEL. CABLE
 - HE HECO CABLE

PHILLIP K. H. YEE & ASSOCIATES
CONSULTING ENGINEERS
243 Liliuokalani Ave., Rm. 101
Honolulu, Hawaii 96813

CURTIS Q. H. YEE
REGISTERED PROFESSIONAL ENGINEER
No. 2624-E
HAWAII, U.S.A.

THIS WORK WAS PREPARED BY ME
OR UNDER MY SUPERVISION.

STATE OF HAWAII
DEPARTMENT OF TRANSPORTATION
HIGHWAYS DIVISION

WAIAWA INTERCHANGE
WATER SPRINKLER SYSTEM
PROJ # I-H-1(102)-8

SPRINKLER PLAN
ZONE I-7