SHEET NO. DESCRIPTION  1 TITLE SHEET  2 STANDARD PLANS  3 GENERAL NOTES & LEGEND		
1 TITLE SHEET 2 STANDARD PLANS 3 GENERAL NOTES & LEGEND	INDEX TO DRAWINGS	
2 STANDARD PLANS 3 GENERAL NOTES & LEGEND	SHEET NO.	DESCRIPTION
3 GENERAL NOTES & LEGEND	1	TITLE SHEET
THE TOTAL OR LEGEND	2	STANDARD PLANS
	3	GENERAL NOTES & LEGEND
4 DETAILS	4	DETAILS
5 PLAN	5	PLAN
6-11 STRUCTURAL PLANS	6–11	STRUCTURAL PLANS
12–14 ELECTRICAL PLANS	12–14	ELECTRICAL PLANS
15–16 CROSS SECTIONS	15–16	CROSS SECTIONS

APRIL 1998 DATE

STATE OF HAWAII


## DEPARTMENT OF TRANSPORTATION

HIGHWAYS DIVISION HONOLULU, HAWAII "AS-BUILT" PLANS FOR

## FARRINGTON HIGHWAY RETAINING WALL

VICINITY OF AWANUI ST. TO WAIPIO POINT ACCESS RD. F.A. PROJECT NO. STP-7101(1)


> DISTRICT OF EWA ISLAND OF OAHU

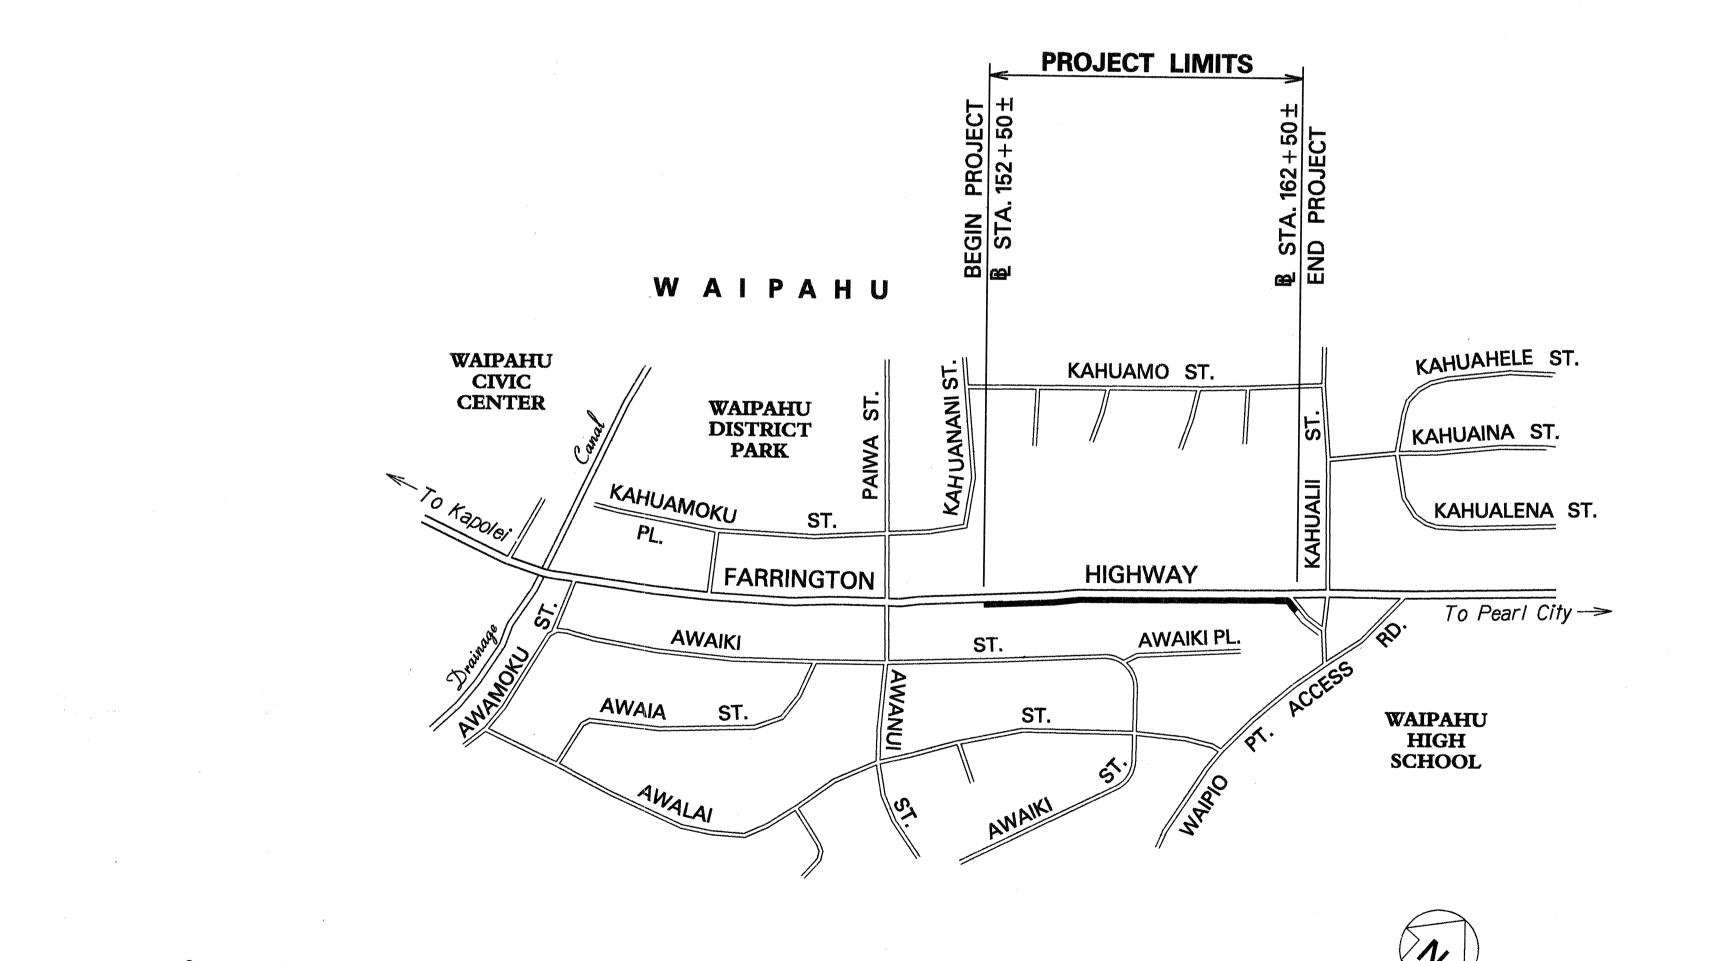

SCALE IN HUNDREDS OF FEET

LAYOUT PLAN

LENGTH OF PROJECT.....0.19 MILES

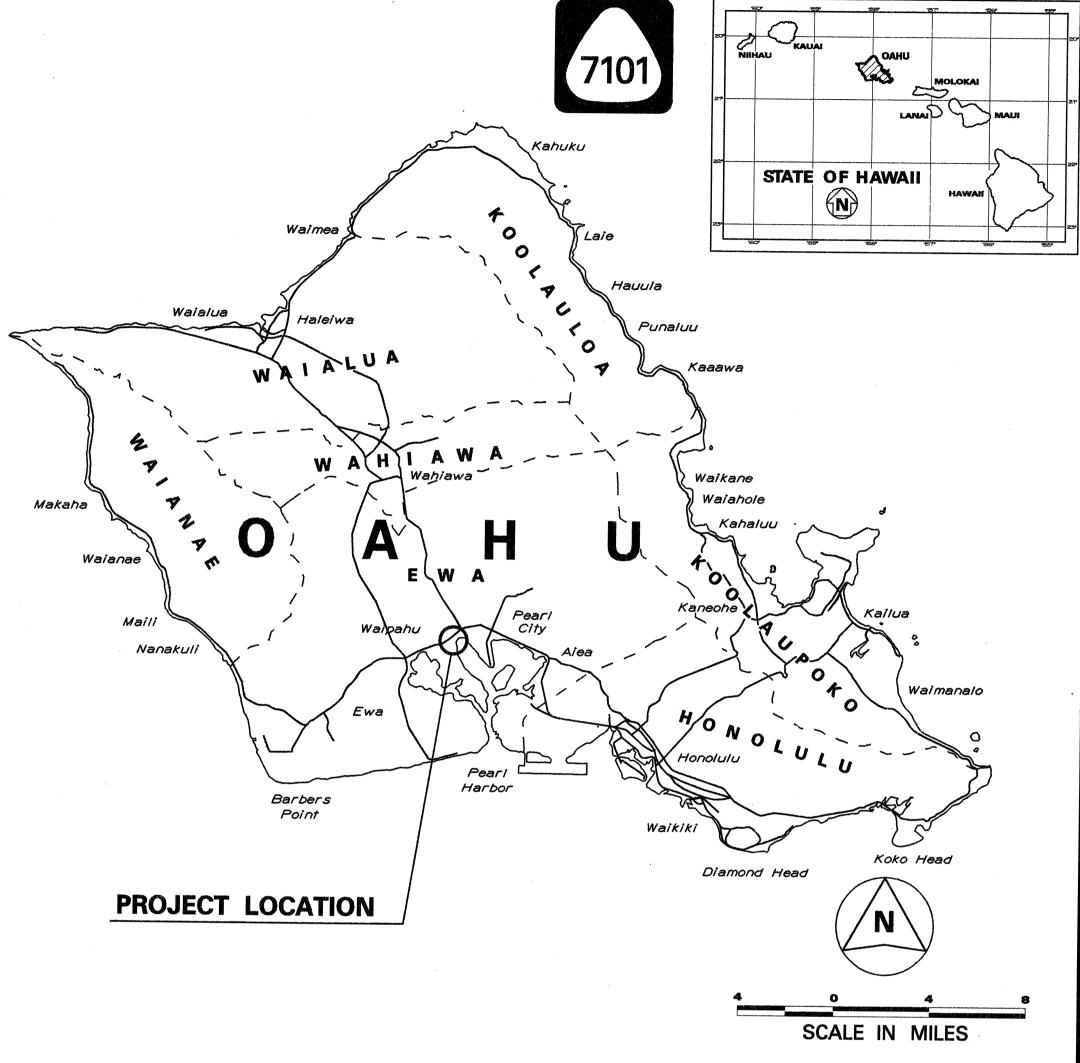

FED. ROAD DIST. NO.

FED. AID PROJ. NO.

STP-7101(1)

FISCAL SHEET YEAR NO.

SHEETS

MILE POST 2.12 TO MILE POST 2.21

CHANGES MADE DURING CONSTRUCTION HAVE BEEN INCORPORATED ON THESE PLANS EXCEPT CHANGES IN THE ORIGINAL THEORETICAL QUANTITIES. FOR ACTUAL QUANTITIES, REFER TO PROJECT LEDGER AND/OR COMPUTATION BOOK.

RESIDENT ENGINEER

DATE

DEPARTMENT OF TRANSPORTATION STATE OF HAWAII

**APPROVED:** 

DIR. OF TRANSPORTATION

5/11/98 DATE