


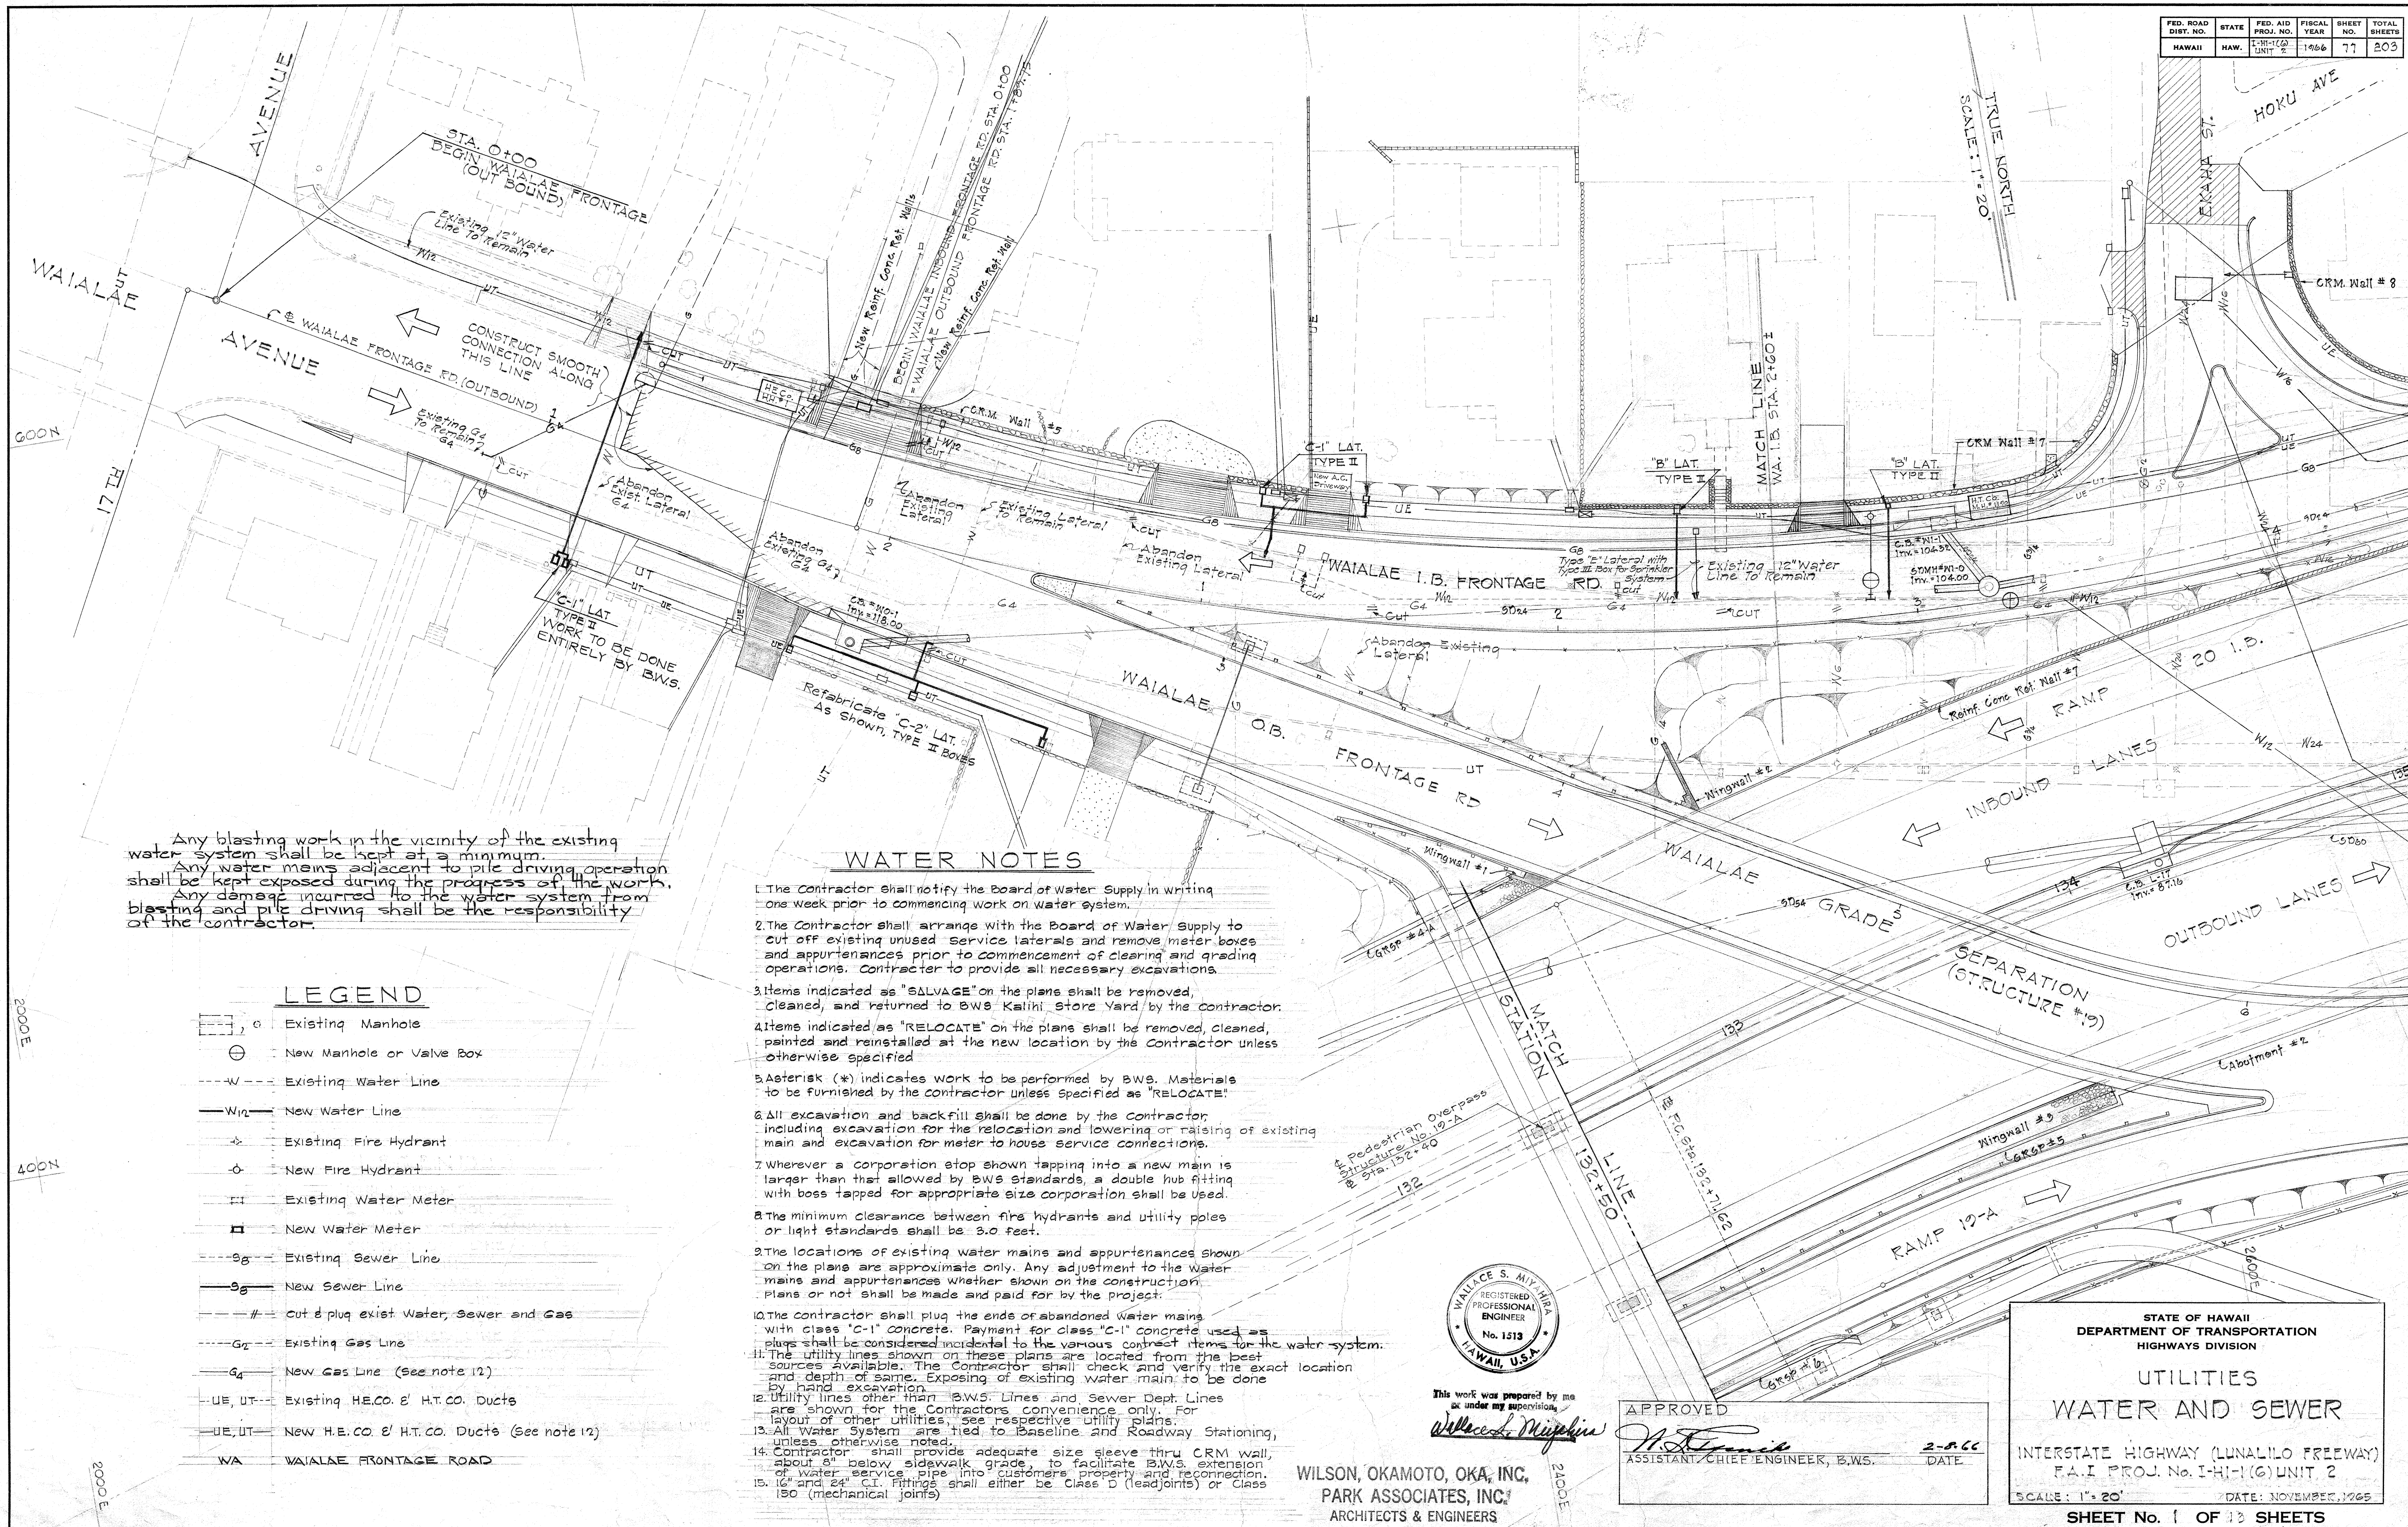


Any blasting work in the vicinity of the existing water system shall be kept at a minimum. Any water mains adjacent to pile driving operation shall be kept exposed during the progress of the work. Any damage incurred to the water system from blasting and pile driving shall be the responsibility of the contractor.

WATER NOTES

- The Contractor shall notify the Board of Water Supply in writing one week prior to commencing work on water system.
- The Contractor shall arrange with the Board of Water Supply to cut off existing unused service laterals and remove meter boxes and appurtenances prior to commencement of clearing and grading operations. Contractor to provide all necessary excavations.
- Items indicated as "SALVAGE" on the plans shall be removed, cleaned, and returned to BWS Kalihli Store Yard by the Contractor.
- Items indicated as "RELOCATE" on the plans shall be removed, cleaned, painted and reinstalled at the new location by the Contractor unless otherwise specified.
- Asterisk (*) indicates work to be performed by BWS. Materials to be furnished by the contractor unless specified as "RELOCATE".
- All excavation and backfill shall be done by the Contractor, including excavation for the relocation and lowering or raising of existing main and excavation for meter to house service connections.
- Wherever a corporation stop shown tapping into a new main is larger than that allowed by BWS standards, a double hub fitting with boss tapped for appropriate size corporation shall be used.
- The minimum clearance between fire hydrants and utility poles or light standards shall be 3.0 feet.
- The locations of existing water mains and appurtenances shown on the plans are approximate only. Any adjustment to the water mains and appurtenances whether shown on the construction plans or not shall be made and paid for by the project.
- The contractor shall plug the ends of abandoned water mains with class "C-1" concrete. Payment for class "C-1" concrete used as plugs shall be considered incidental to the various contract items for the water system.
- The utility lines shown on these plans are located from the best sources available. The Contractor shall check and verify the exact location and depth of same. Exposing of existing water main to be done by hand excavation.
- Utility lines other than BWS Lines and Sewer Dept. Lines are shown for the Contractor's convenience only. For layout of other utilities, see respective utility plans.
- All Water System are tied to Baseline and Roadway Stationing, unless otherwise noted.
- Contractor shall provide adequate size sleeve thru CRM wall, about 8" below sidewalk grade, to facilitate BWS extension of water service pipe into customers property and reconnection.
- 16" and 24" C.I. Fittings shall either be Class D (leadjoints) or Class 130 (mechanical joints)

LEGEND

- Existing Manhole
- New Manhole or Valve Box
- Existing Water Line
- New Water Line
- Existing Fire Hydrant
- New Fire Hydrant
- Existing Water Meter
- New Water Meter
- Existing Sewer Line
- New Sewer Line
- Cut & plug exist Water, Sewer and Gas
- Existing Gas Line
- New Gas Line (See note 12)
- Existing H.E.CO. & H.T.CO. Ducts
- New H.E.CO. & H.T.CO. Ducts (See note 12)
- WAIALAE FRONTAGE ROAD

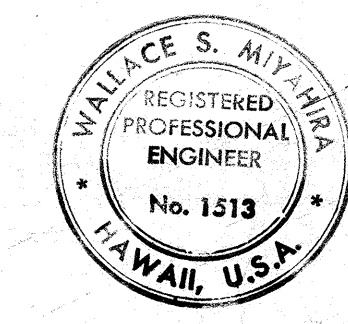

This work was prepared by me or under my supervision.
Wallace S. Miyahira
 REGISTERED PROFESSIONAL ENGINEER
 No. 1313
 HAWAII, U.S.A.

APPROVED

M. J. ...
 ASSISTANT CHIEF ENGINEER, B.W.S.

DATE

WILSON, OKAMOTO, OKA, INC.,
 PARK ASSOCIATES, INC.,
 ARCHITECTS & ENGINEERS

STATE OF HAWAII
 DEPARTMENT OF TRANSPORTATION
 HIGHWAYS DIVISION

UTILITIES
 WATER AND SEWER

INTERSTATE HIGHWAY (LUNALILO FREEWAY)
 F.A.I. PROJ. No. I-H-1(6) UNIT 2

SCALE: 1" = 20'
 DATE: NOVEMBER, 1965

SHEET No. 1 OF 13 SHEETS

FEED ROAD	STATE	FEED. NO.	FEED. YEAR	FEED. NO.	FEED. YEAR	TOTAL
FEED. NO.	FEED. YEAR	FEED. NO.	FEED. YEAR	FEED. NO.	FEED. YEAR	FEED. YEAR
FEED. NO.	FEED. YEAR	FEED. NO.	FEED. YEAR	FEED. NO.	FEED. YEAR	FEED. YEAR
SEWER NOTES

- Existing Sewer Lines shown on the plans are based on existing records of varying degree of accuracy and completeness, verified wherever possible by field surveys. The Contractor shall verify actual location and inverts of existing lines, and shall be required to make adjustment to any new or existing sewer system wherever directed by the Engineer.
- Adjust existing sewer manholes and manhole frames and covers within proposed roadway to fit new roadway finished grades.
- If laterals other than those shown on the plans are exposed during construction, the same shall be cut and plugged, or extended and reconnected as required.
- All services connected to existing sewer mains which are to be abandoned or removed shall be reconnected to new sewer mains if services are required.
- All work involved in installation of new sewer mains, connection of existing house sewers to new sewer line, construction of concrete jackets around sewer mains, extension of laterals to new property line, and cutting and plugging of abandoned sewer lines and laterals shall be performed in accordance with the latest City and County Standard Sewer Details and Specifications and under the supervision of an Inspector or Representative of the Division of Sewers, City and County of Honolulu.
- Concrete blocks and cradles shall be placed for all sewer mains and laterals.
- Salvaged 21 inch diameter manhole frames and covers may be used only for manholes at end of lines and only if the depth of manholes are 5 feet or less. All salvaged 24 inch frames and covers shall be used before 21 inch frames and covers are used.
- All services shall be maintained at all times during construction. Alterations to service lines shall be done with the least amount of disturbance to the existing services to the various houses.
- All trees, lawns, shrubbery, fences, etc., disturbed in the process of performing work on sewer service lines, shall be restored by the Contractor to the satisfaction of the Engineer. Such restoration work will not be paid for separately, but shall be considered as incidental to the various contract items for the Sewer System.
- Contractor shall notify the Division of Sewers two (2) days prior to commencement of sewer work.

DATE	BY	DATE	BY
DATE	BY	DATE	BY
Curve Data
 $\Delta = 4^{\circ}12'10"$
 $\Delta/2 = 2^{\circ}06'05"$
 $R = 3000.00$
 $T = 113.14$
 $C = 226.11$
 $L_c = 226.17$

STA. 143+18
 (SEE SKETCH BELOW)
 1- F.H. # 2320 (Relocated)
 1- 6" G.V. 150" (Relocated)
 1- 24" x 6" B.O. Tee (Tilt Down)
 1- Type "C" M.H. 2.0' Deep
 24" L.F. 6" C.I. Pipe
 4- Conc. Blocks
 1- 20" M.H. Fr. & Cover (Relocated)
 1- 6" 1/8 C.I. Bend
 1- 6" 1/4 C.I. Bend
 TO BE RELOCATED
 1- F.H. # 2320
 1- 6" G.V. 150"
 1- 20" M.H. Fr. & Cover

DEMOLISH
 1- Type "C" M.H.

STA. 145+02
 STA. 146+13
 CONNECTION
 * 60 L.F. 24" C.I. Pipe Cl. 150
 * 2- 24" C.I. 1/8 Bend
 * 1- 24" Sleeve, 18" long
 2- Conc. Blocks w/struct. strut
 Existing Fence

F.H. CONNECTION DETAIL
 AT STA. 145+18
 Scale: 1/8" = 1'-0"


Typical detail of conc. block for 24" x 6" B.O. tee. Actual details to be furnished during construction

APPROVED:
[Signature]
 ASSISTANT CHIEF ENGINEER, B.W.S.
 DATE: 12-11-65
 DIRECTOR, DIVISION OF SEWERS
 DATE: 12-11-65

STATE OF HAWAII
 DEPARTMENT OF TRANSPORTATION
 HIGHWAYS DIVISION
 UTILITIES
 WATER AND SEWER
 INTERSTATE HIGHWAY (LUNALILO FREEWAY)
 F.A.I. PROJ. NO. I-H-1(G) UNIT 2
 SCALE: 1" = 20' DATE: NOVEMBER 1965
 SHEET NO. 4 OF 13 SHEETS

S 11

FED. ROAD DIST. NO.	STATE	FED. AID PROJ. NO.	FISCAL YEAR	SHEET NO.	TOTAL SHEETS
HAWAII	HAW	1-1-1 (6)	1966	81	203

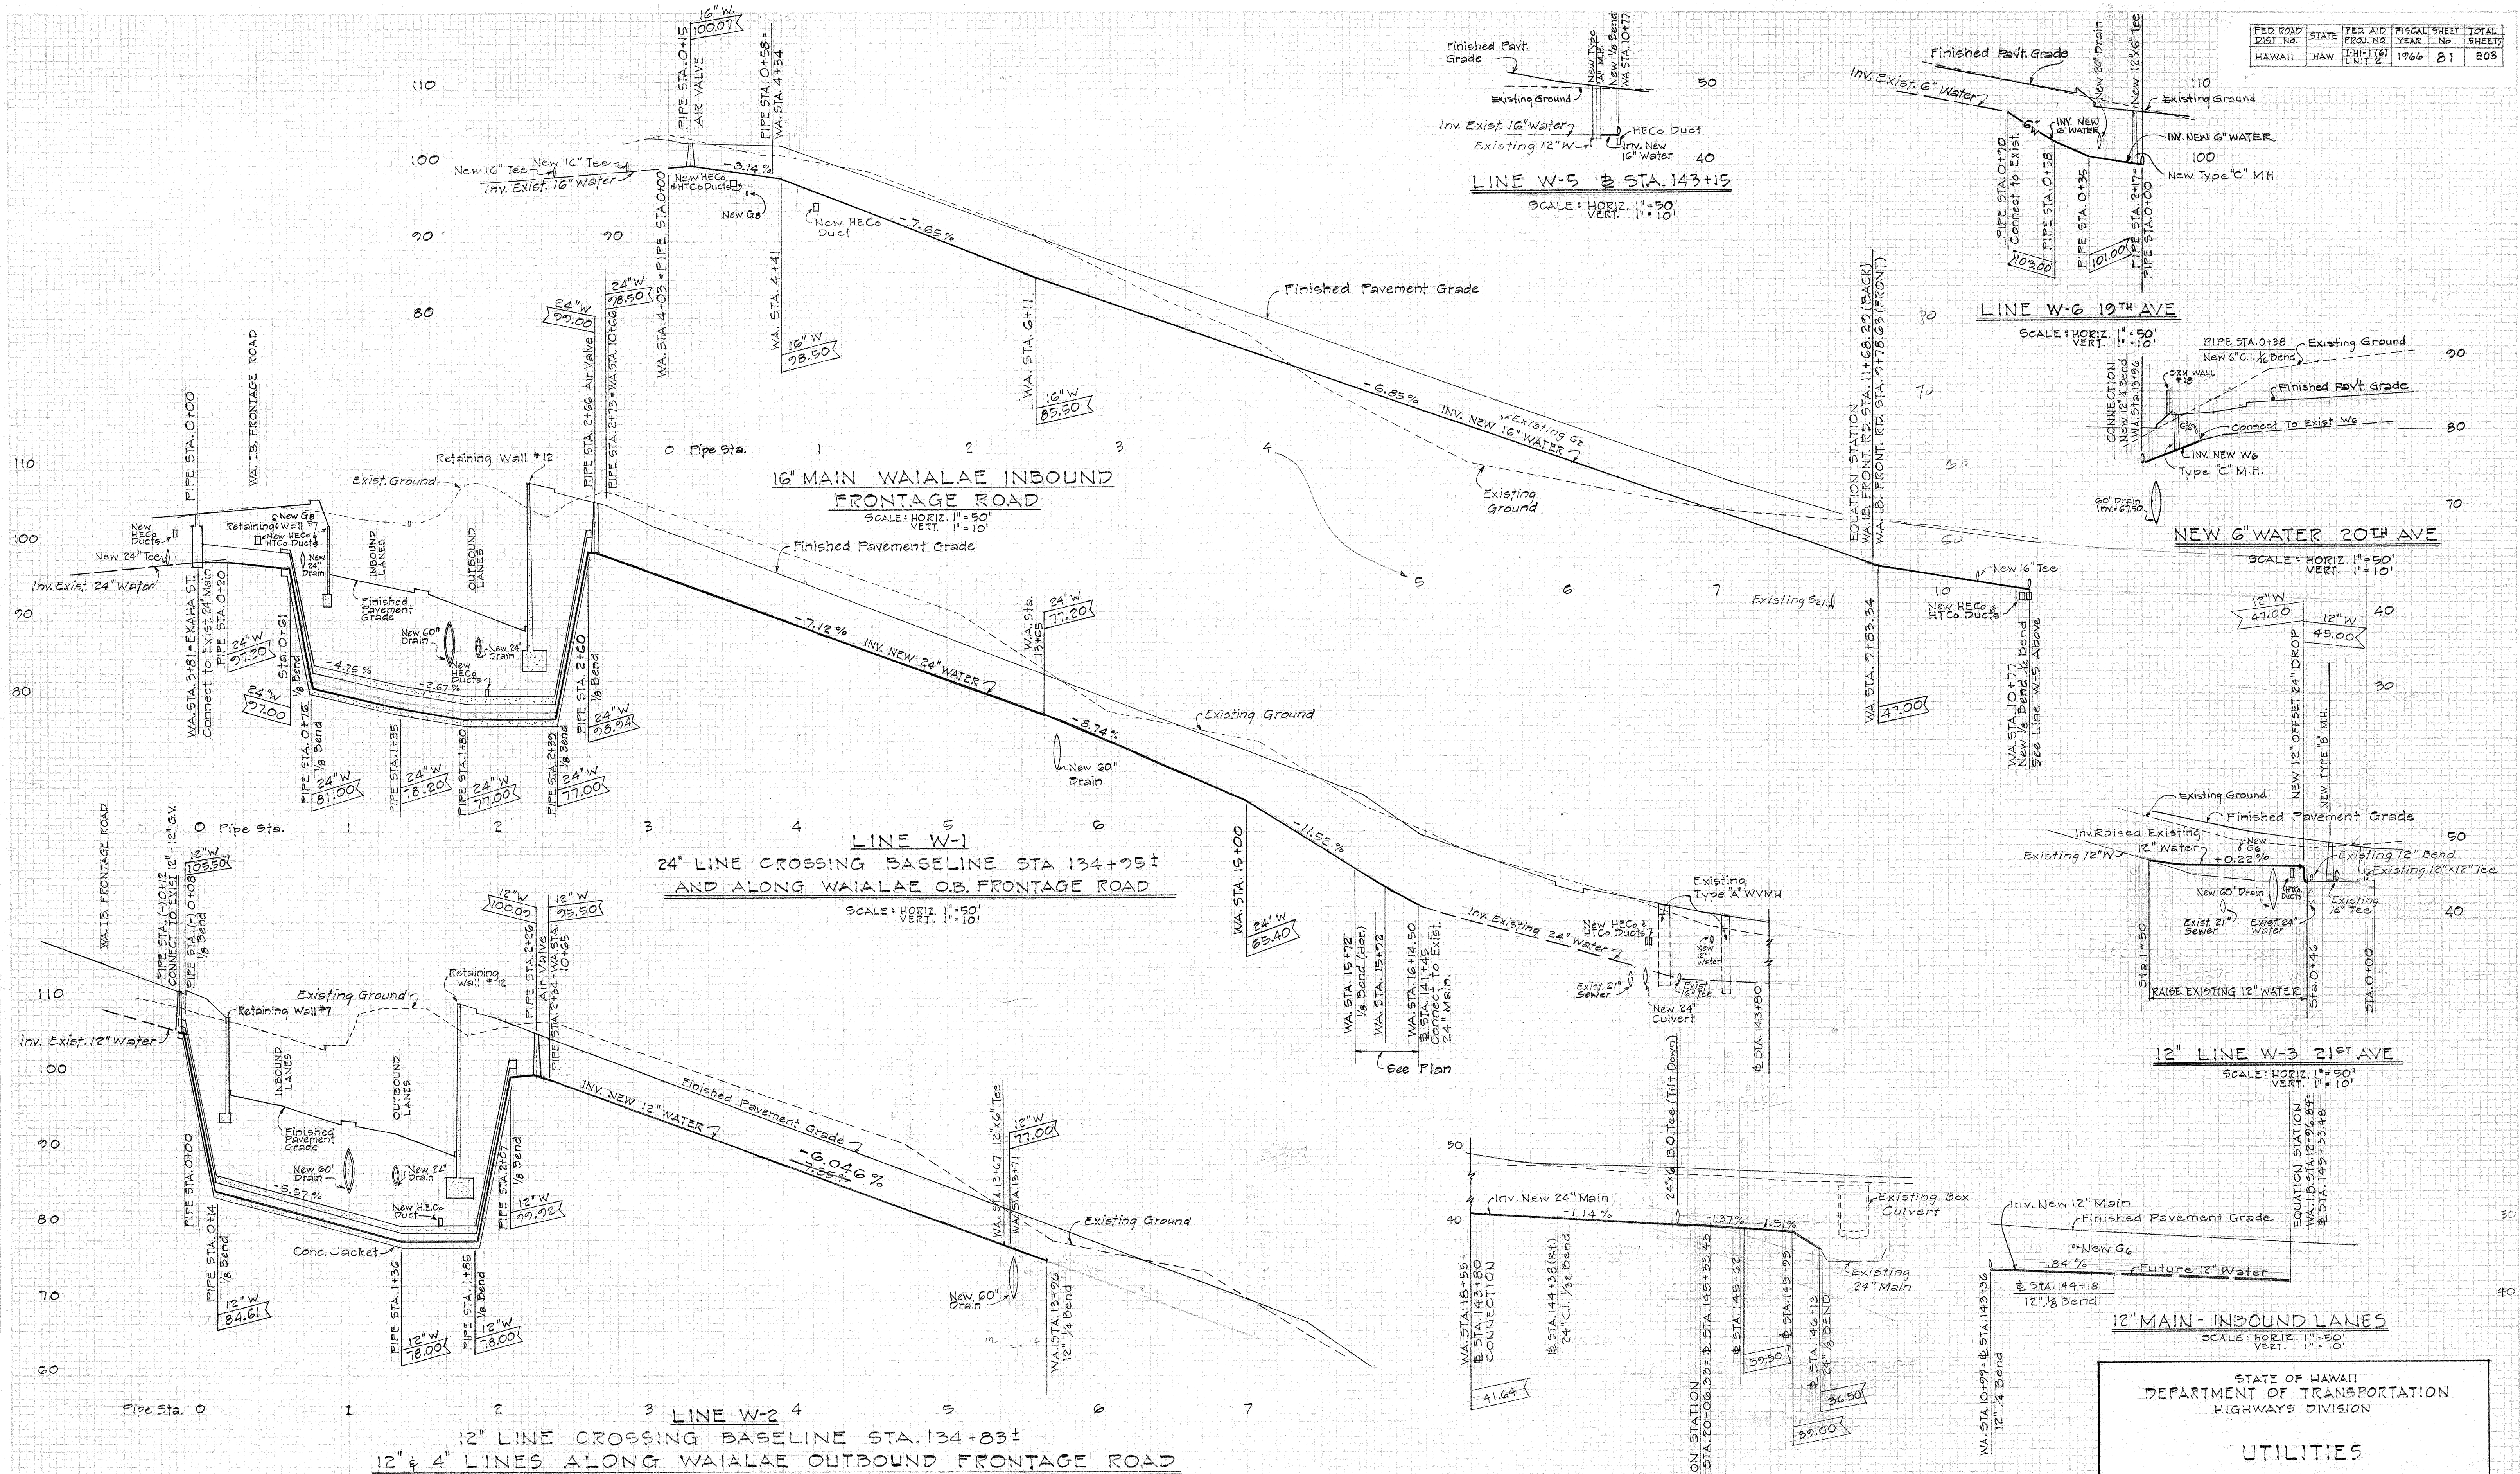

APPROVED:
V. J. P. P.
ASSISTANT CHIEF ENGINEER B.W.S. 2-8-66
DATE


STATE OF HAWAII
DEPARTMENT OF TRANSPORTATION
HIGHWAYS DIVISION

UTILITIES


PROFILE OF WATER SYSTEM

INTERSTATE HIGHWAY (LUNALILO FREEWAY)
F.A.I. PROJECT NO. I-1-1 (6) UNIT 2
SCALE: AS SHOWN DATE: NOVEMBER, 1965
SHEET No. 5 OF 13 SHEETS

FED. ROAD DIST. NO.	STATE	FED. AID PROJ. NO.	FISCAL YEAR	SHEET NO.	TOTAL SHEETS
HAWAII	HAW.	I-HI-1(6) Unit 2	1966	82	209

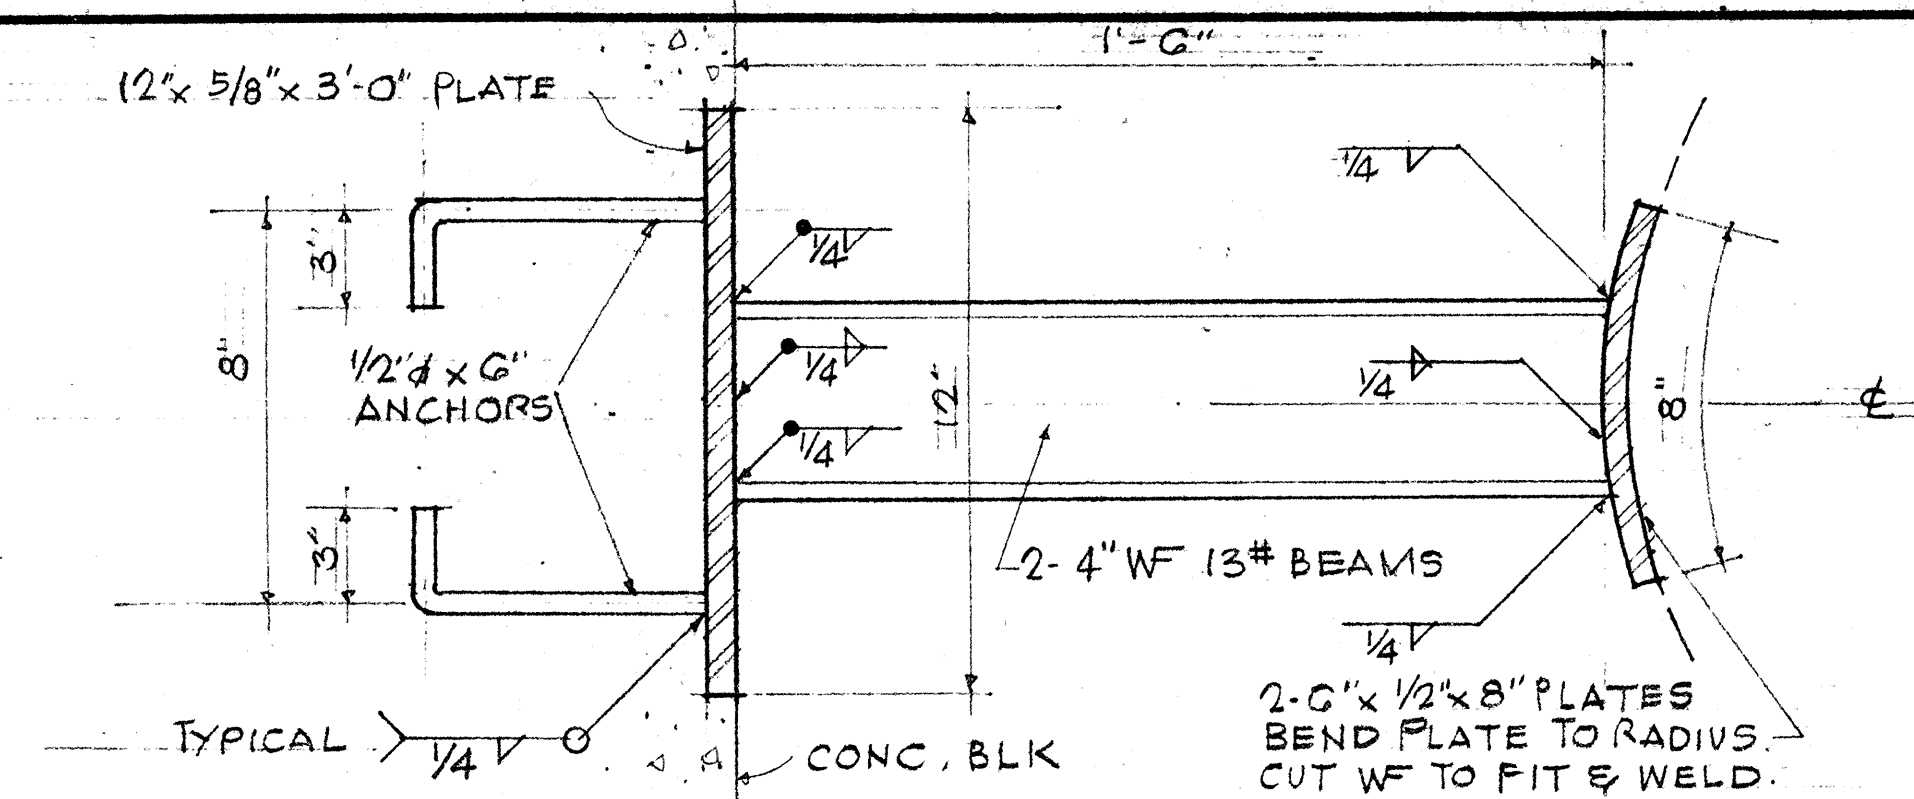


BEAM DETAIL SCALE: 3" = 1'-0"

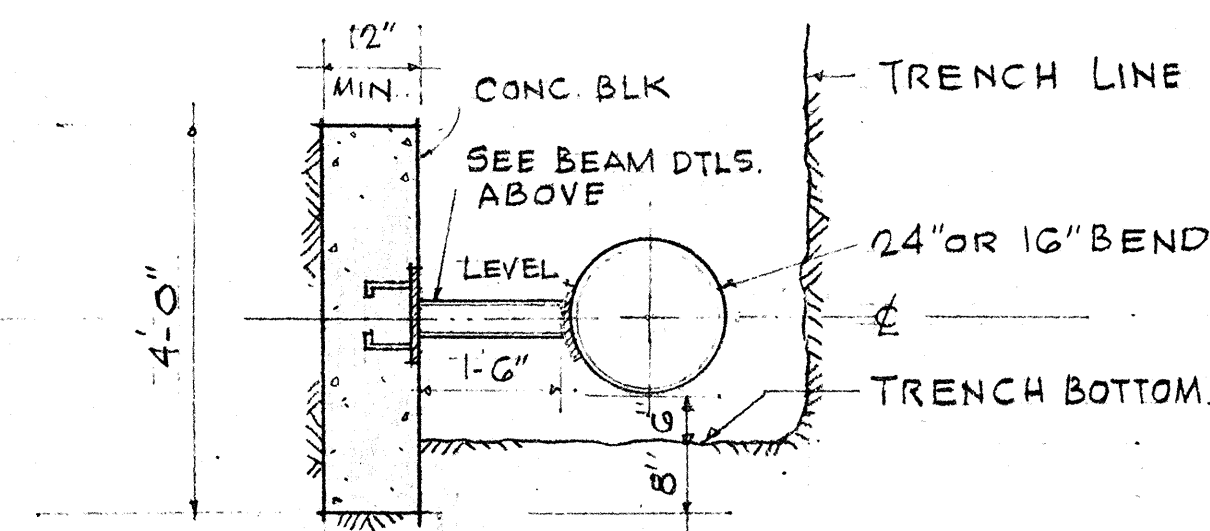


SECTION

SCALE: $1/2" = 1'-0"$

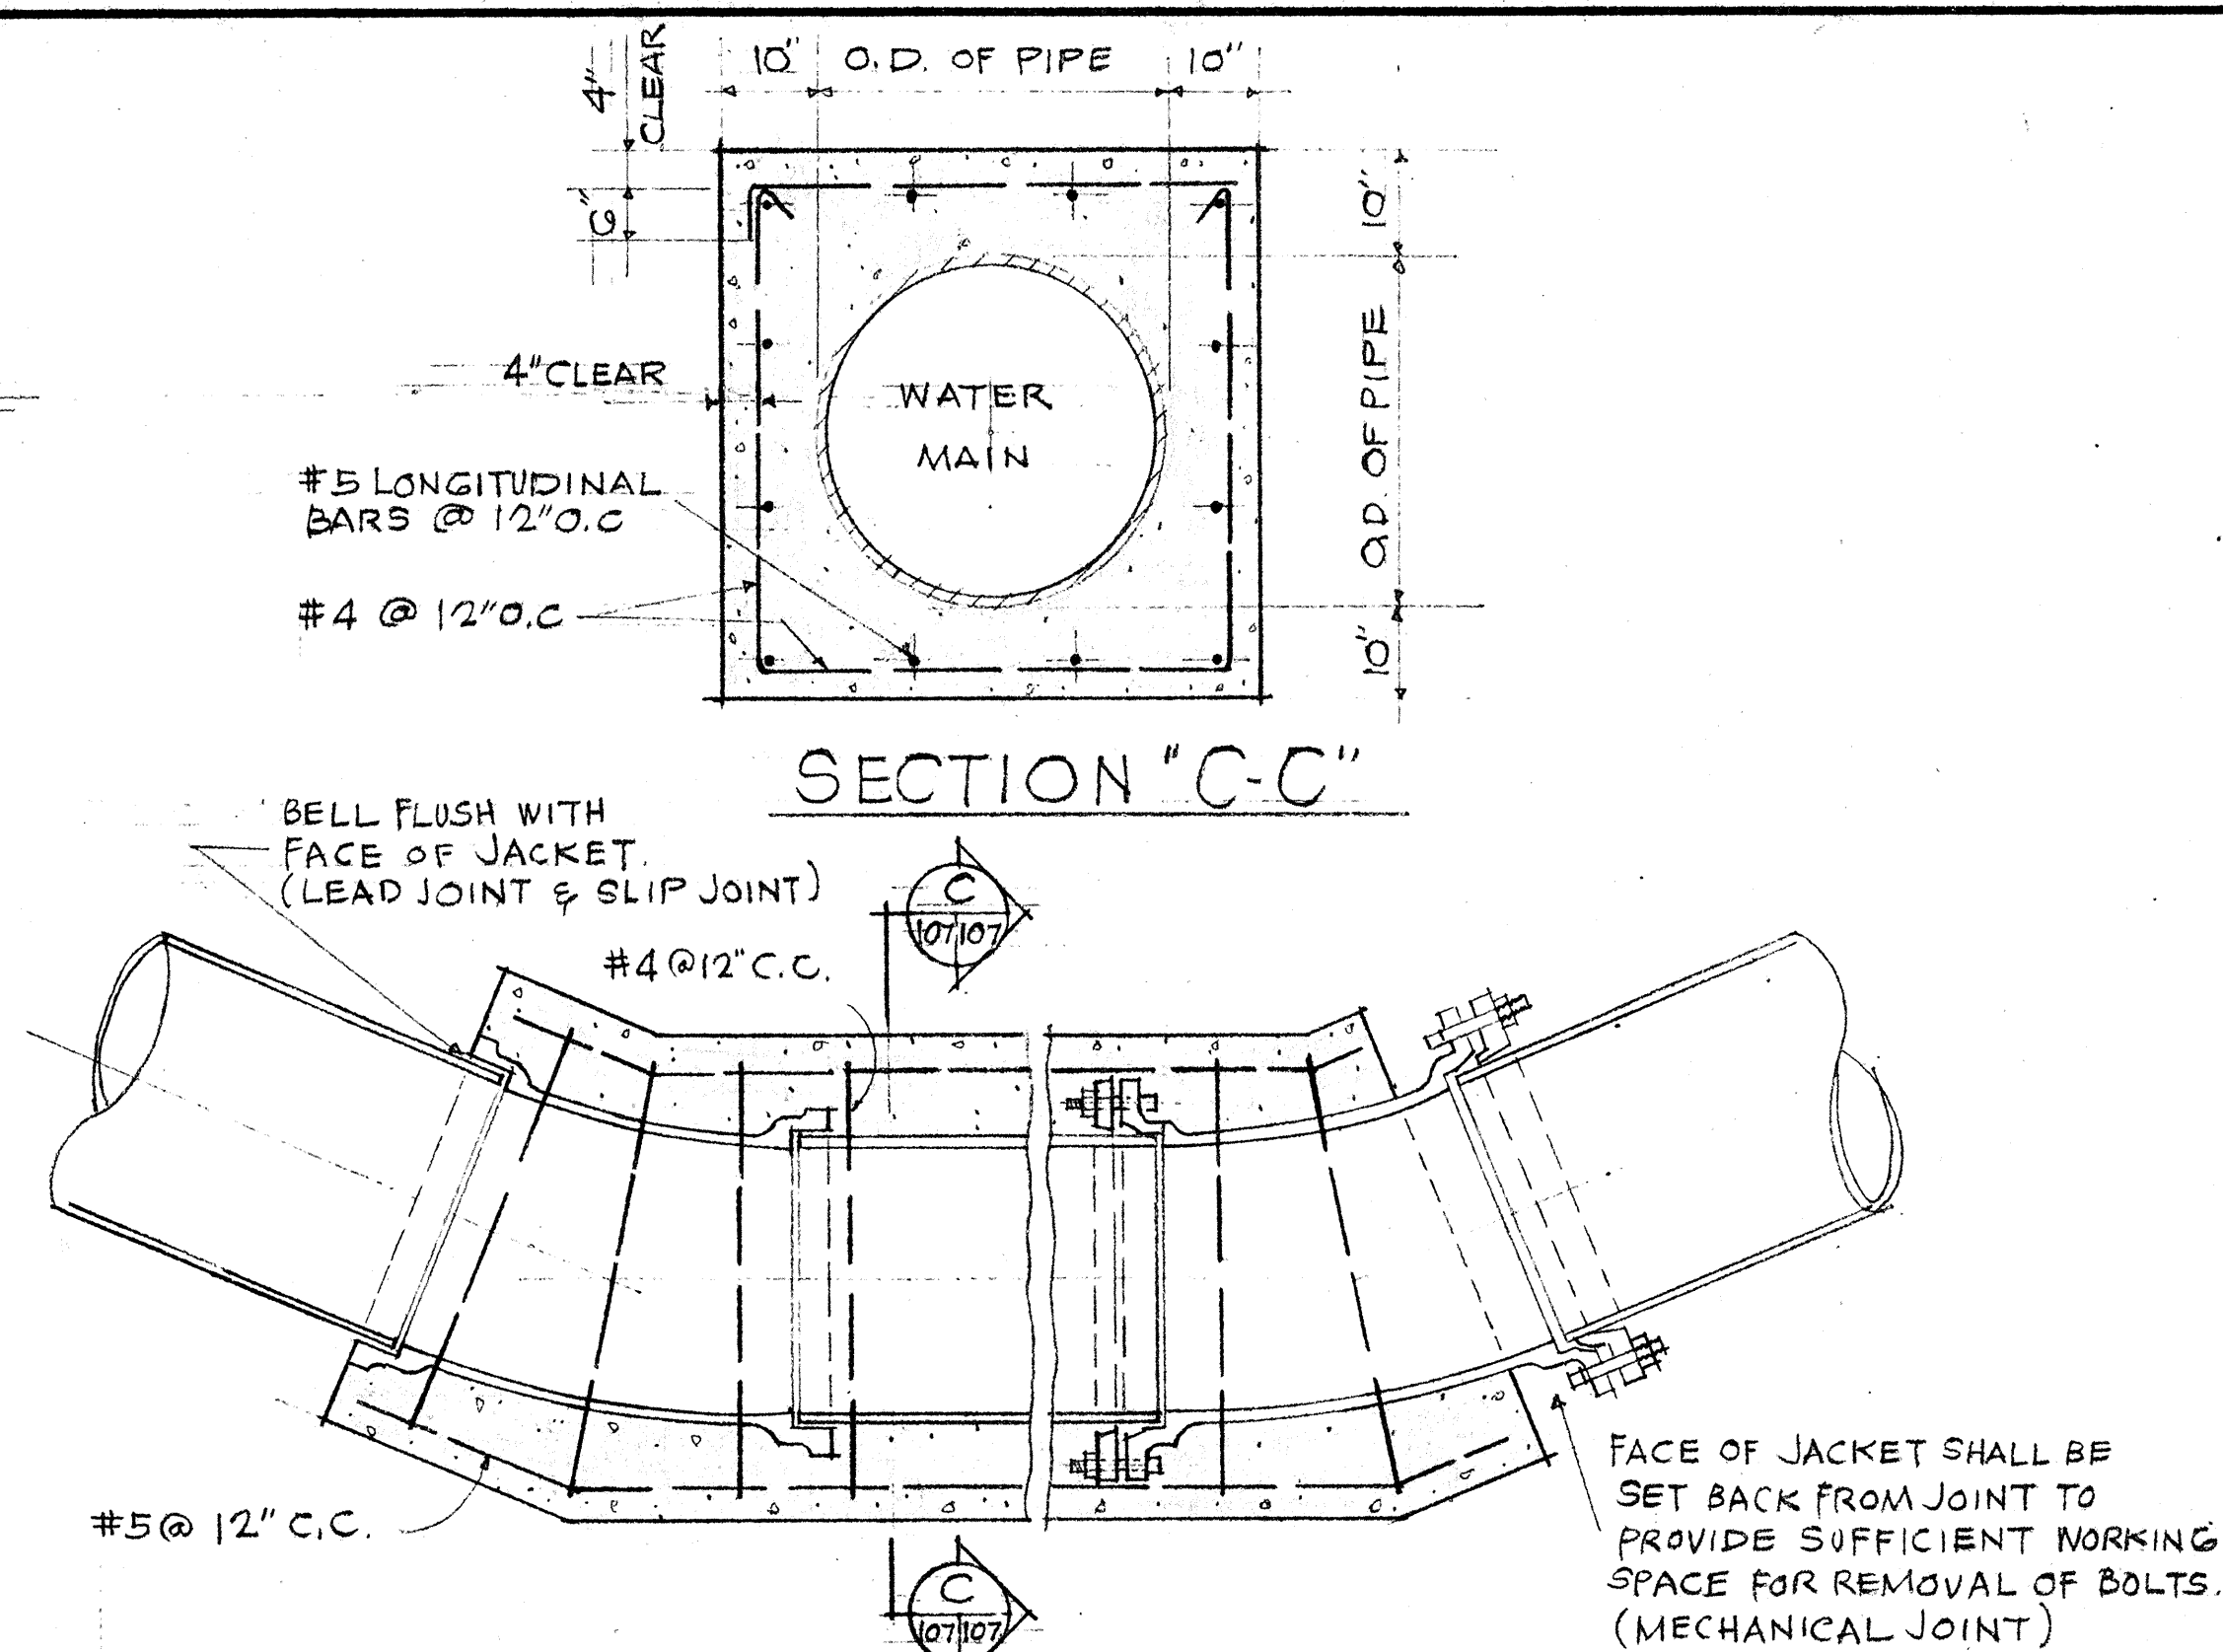

JACKET TO BE POURED AFTER COMPLETION OF TEST. 1/2" DEPTH OF LEAD FOR LEAD JOINT PIPE REQUIRED AT ALL EMBEDDED JOINTS. WHEREVER CONSTRUCTION JOINTS ARE REQUIRED G⁺ RUBBER OR NEOPRENE WATERSTOPS SHALL BE INSTALLED WATERSTOP SHALL BE OF THE TYPE SPECIFIED AND MANUFACTURED BY THE SERVICIZED PRODUCTS CORP, GATE RUBBER CO. OR APPROVED EQUAL.


REINFORCED CONCRETE JACKET

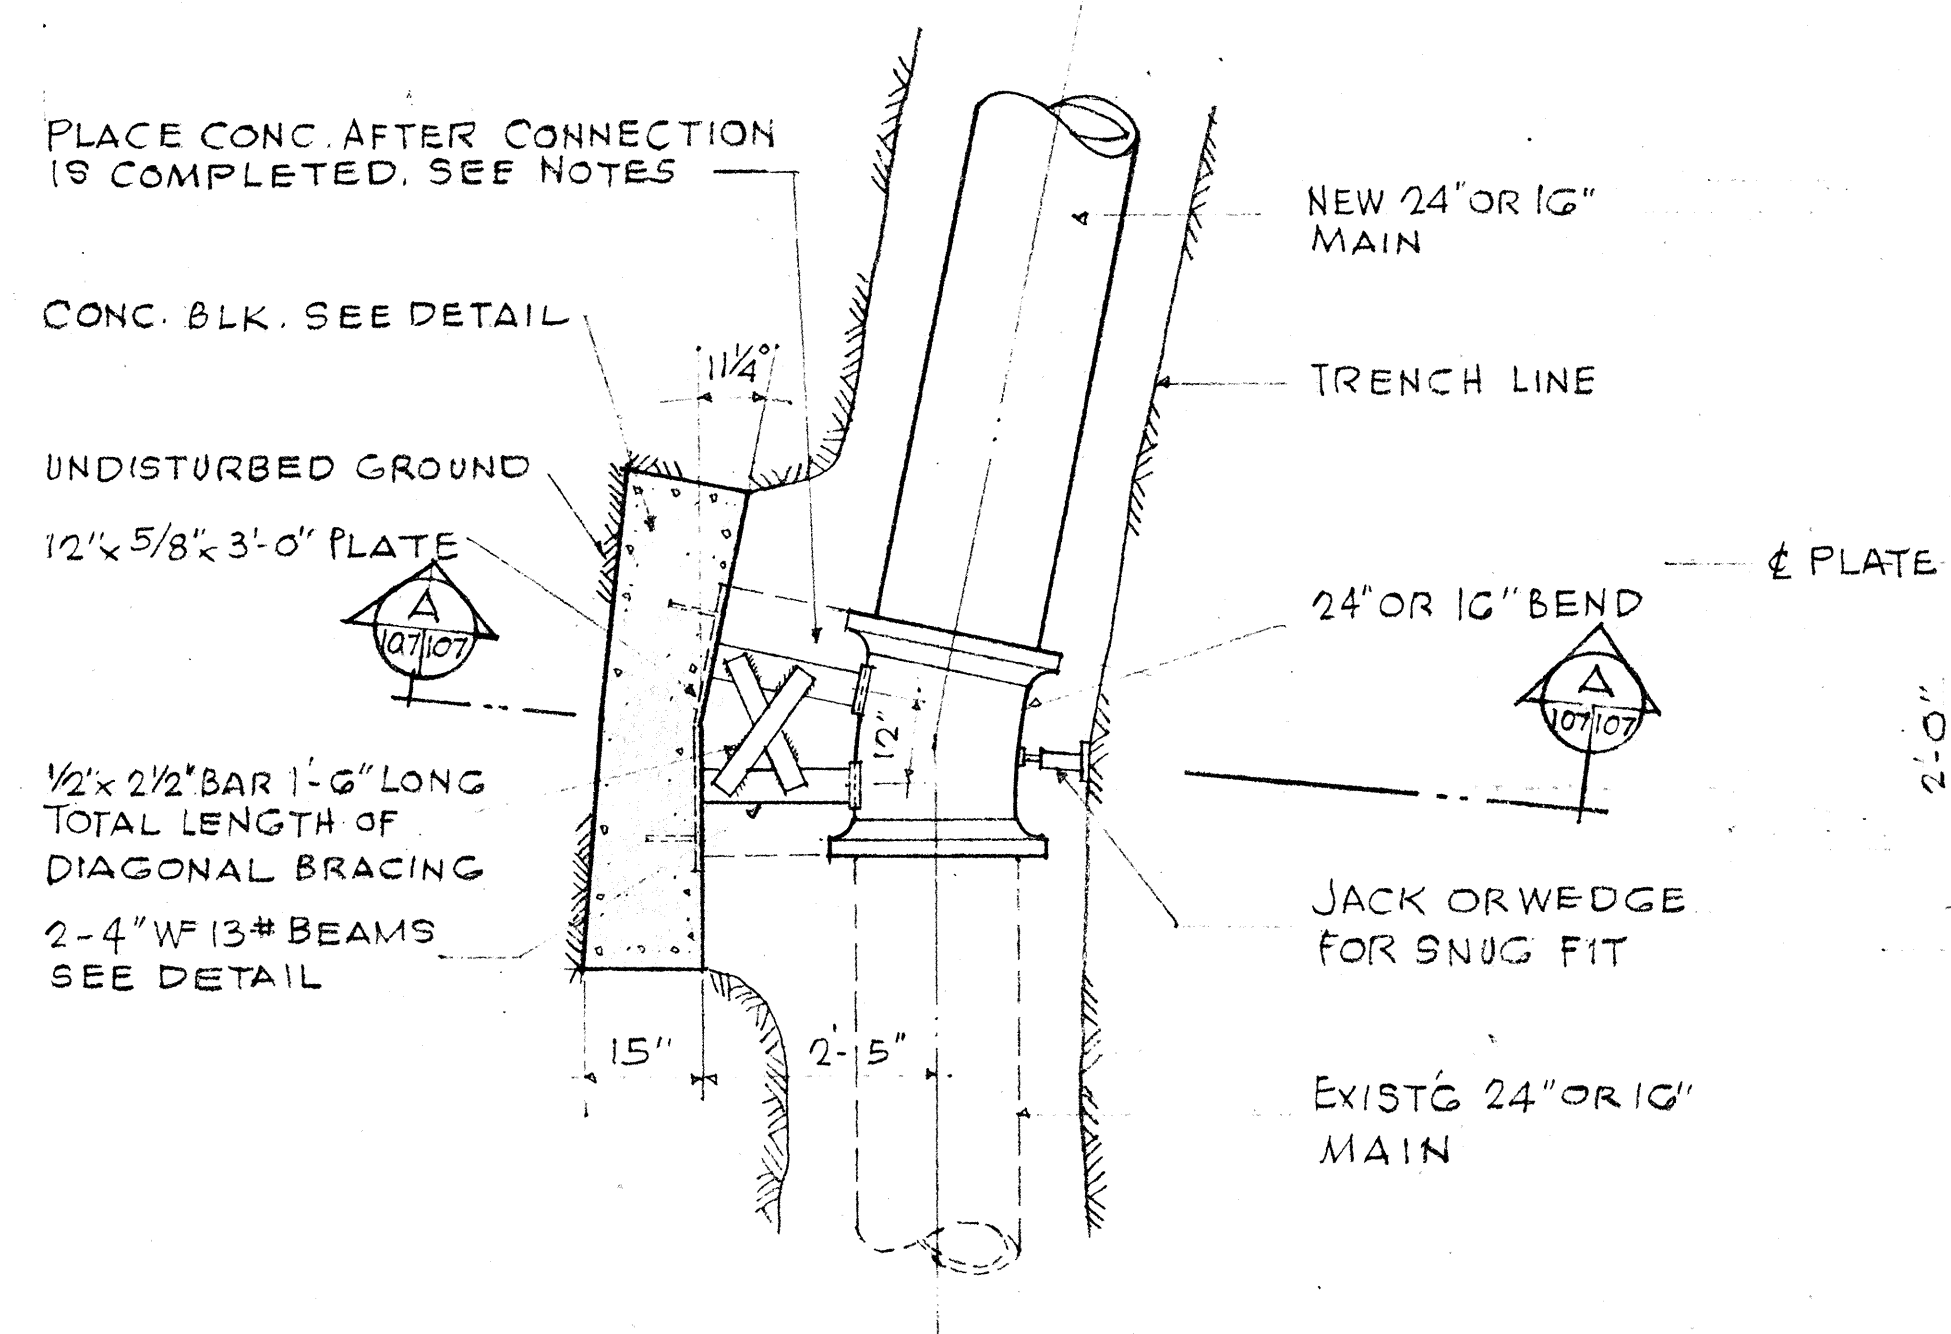

PLAN SCALE: $\frac{1}{2}'' = 1'-0''$

NOTES:

- 1- MINIMUM COVER OVER REINFORCING SHALL BE 3".
- 2- CONCRETE SHALL BE CLASS "B-1" 2500 P.S.I.
- 3- APPROX CONCRETE YARDAGE OF BLK @ 0.93 C.Y.
- 4- DOTTED AREA TO BE FILLED WITH CONC. AFTER CONNECTION IS COMPLETED.

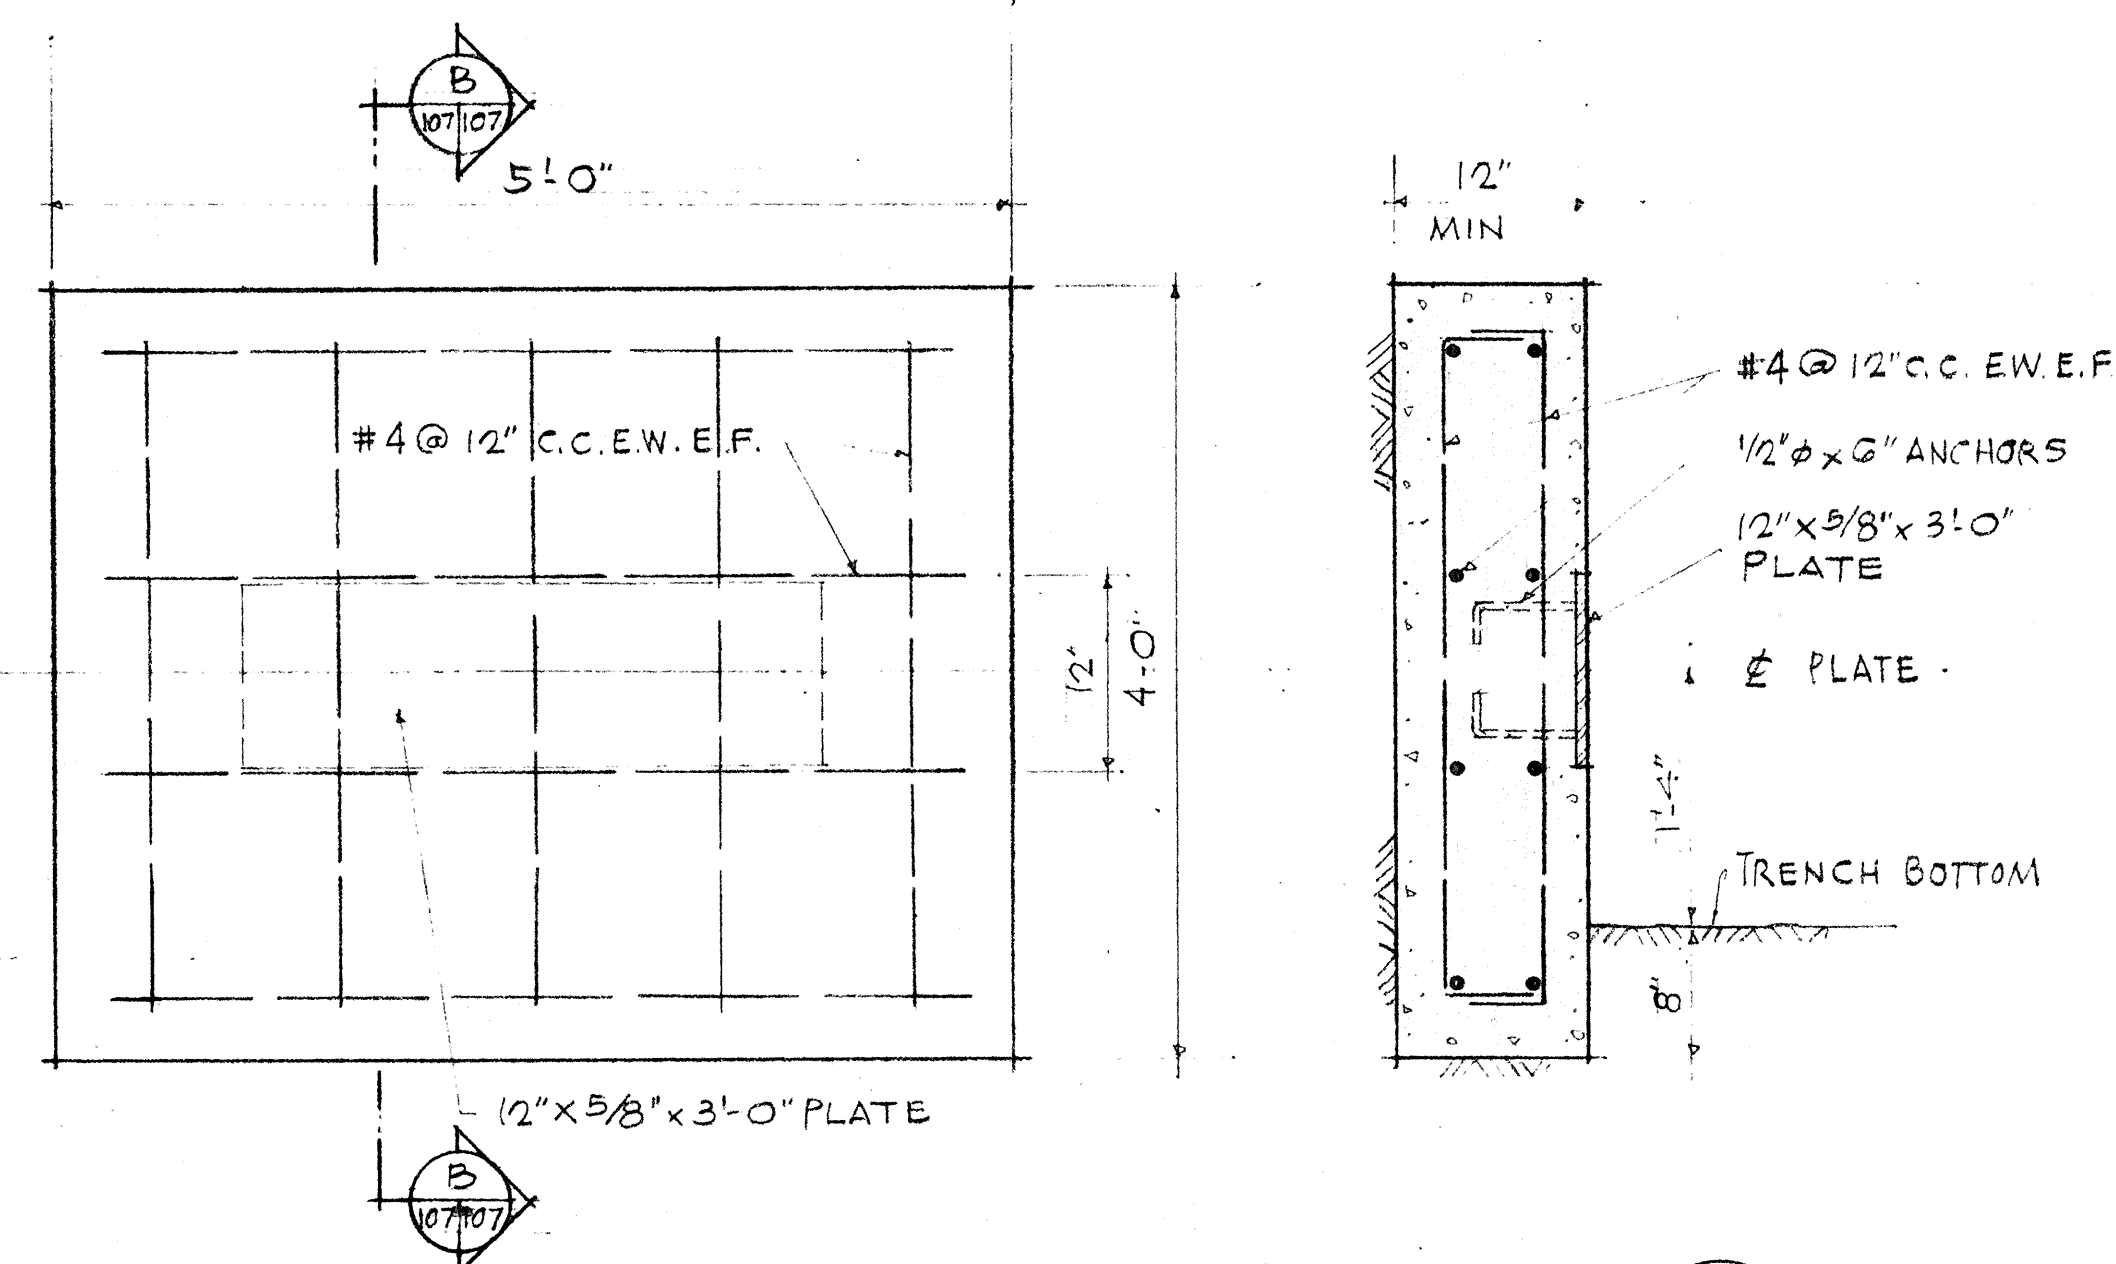

ELEVATION _____ SECTION 
DETAILS OF CONCRETE BLOCK _____

SCALE: 1" = 1'-0"

DETAILS-CONCRETE BLOCK WITH STRUCTURAL
STRUT. (FOR BENDS AT CONNECTIONS)
ALSO: 24" & 16" TEE CONNECTIONS

WILSON, OKAMOTO, OKA, INC.
PARK ASSOCIATES, INC.
ARCHITECTS & ENGINEERS

APPROVED

H. J. Krich
ASSISTANT CHIEF ENGINEER, B.W.S.

2-8-66
DATE

STATE OF HAWAII
DEPARTMENT OF TRANSPORTATION
HIGHWAYS DIVISION




UTILITIES
SPECIAL WATER DETAILS

INTERSTATE HIGHWAY (LUNALILO FREEWAY)
FAI. PROJ. NO. I-HI-1(G) UNIT 2

SCALE: AS SHOWN DATE: NOVEMBER, 1965

SHEET No. 6 OF 13 SHEETS

FED. ROAD DIST. NO.	STATE	FED. AID PROJ. NO.	FISCAL YEAR	SHEET NO.	TOTAL SHEETS
HAWAII	HAW.	1-11-1(6)	1966	83	203

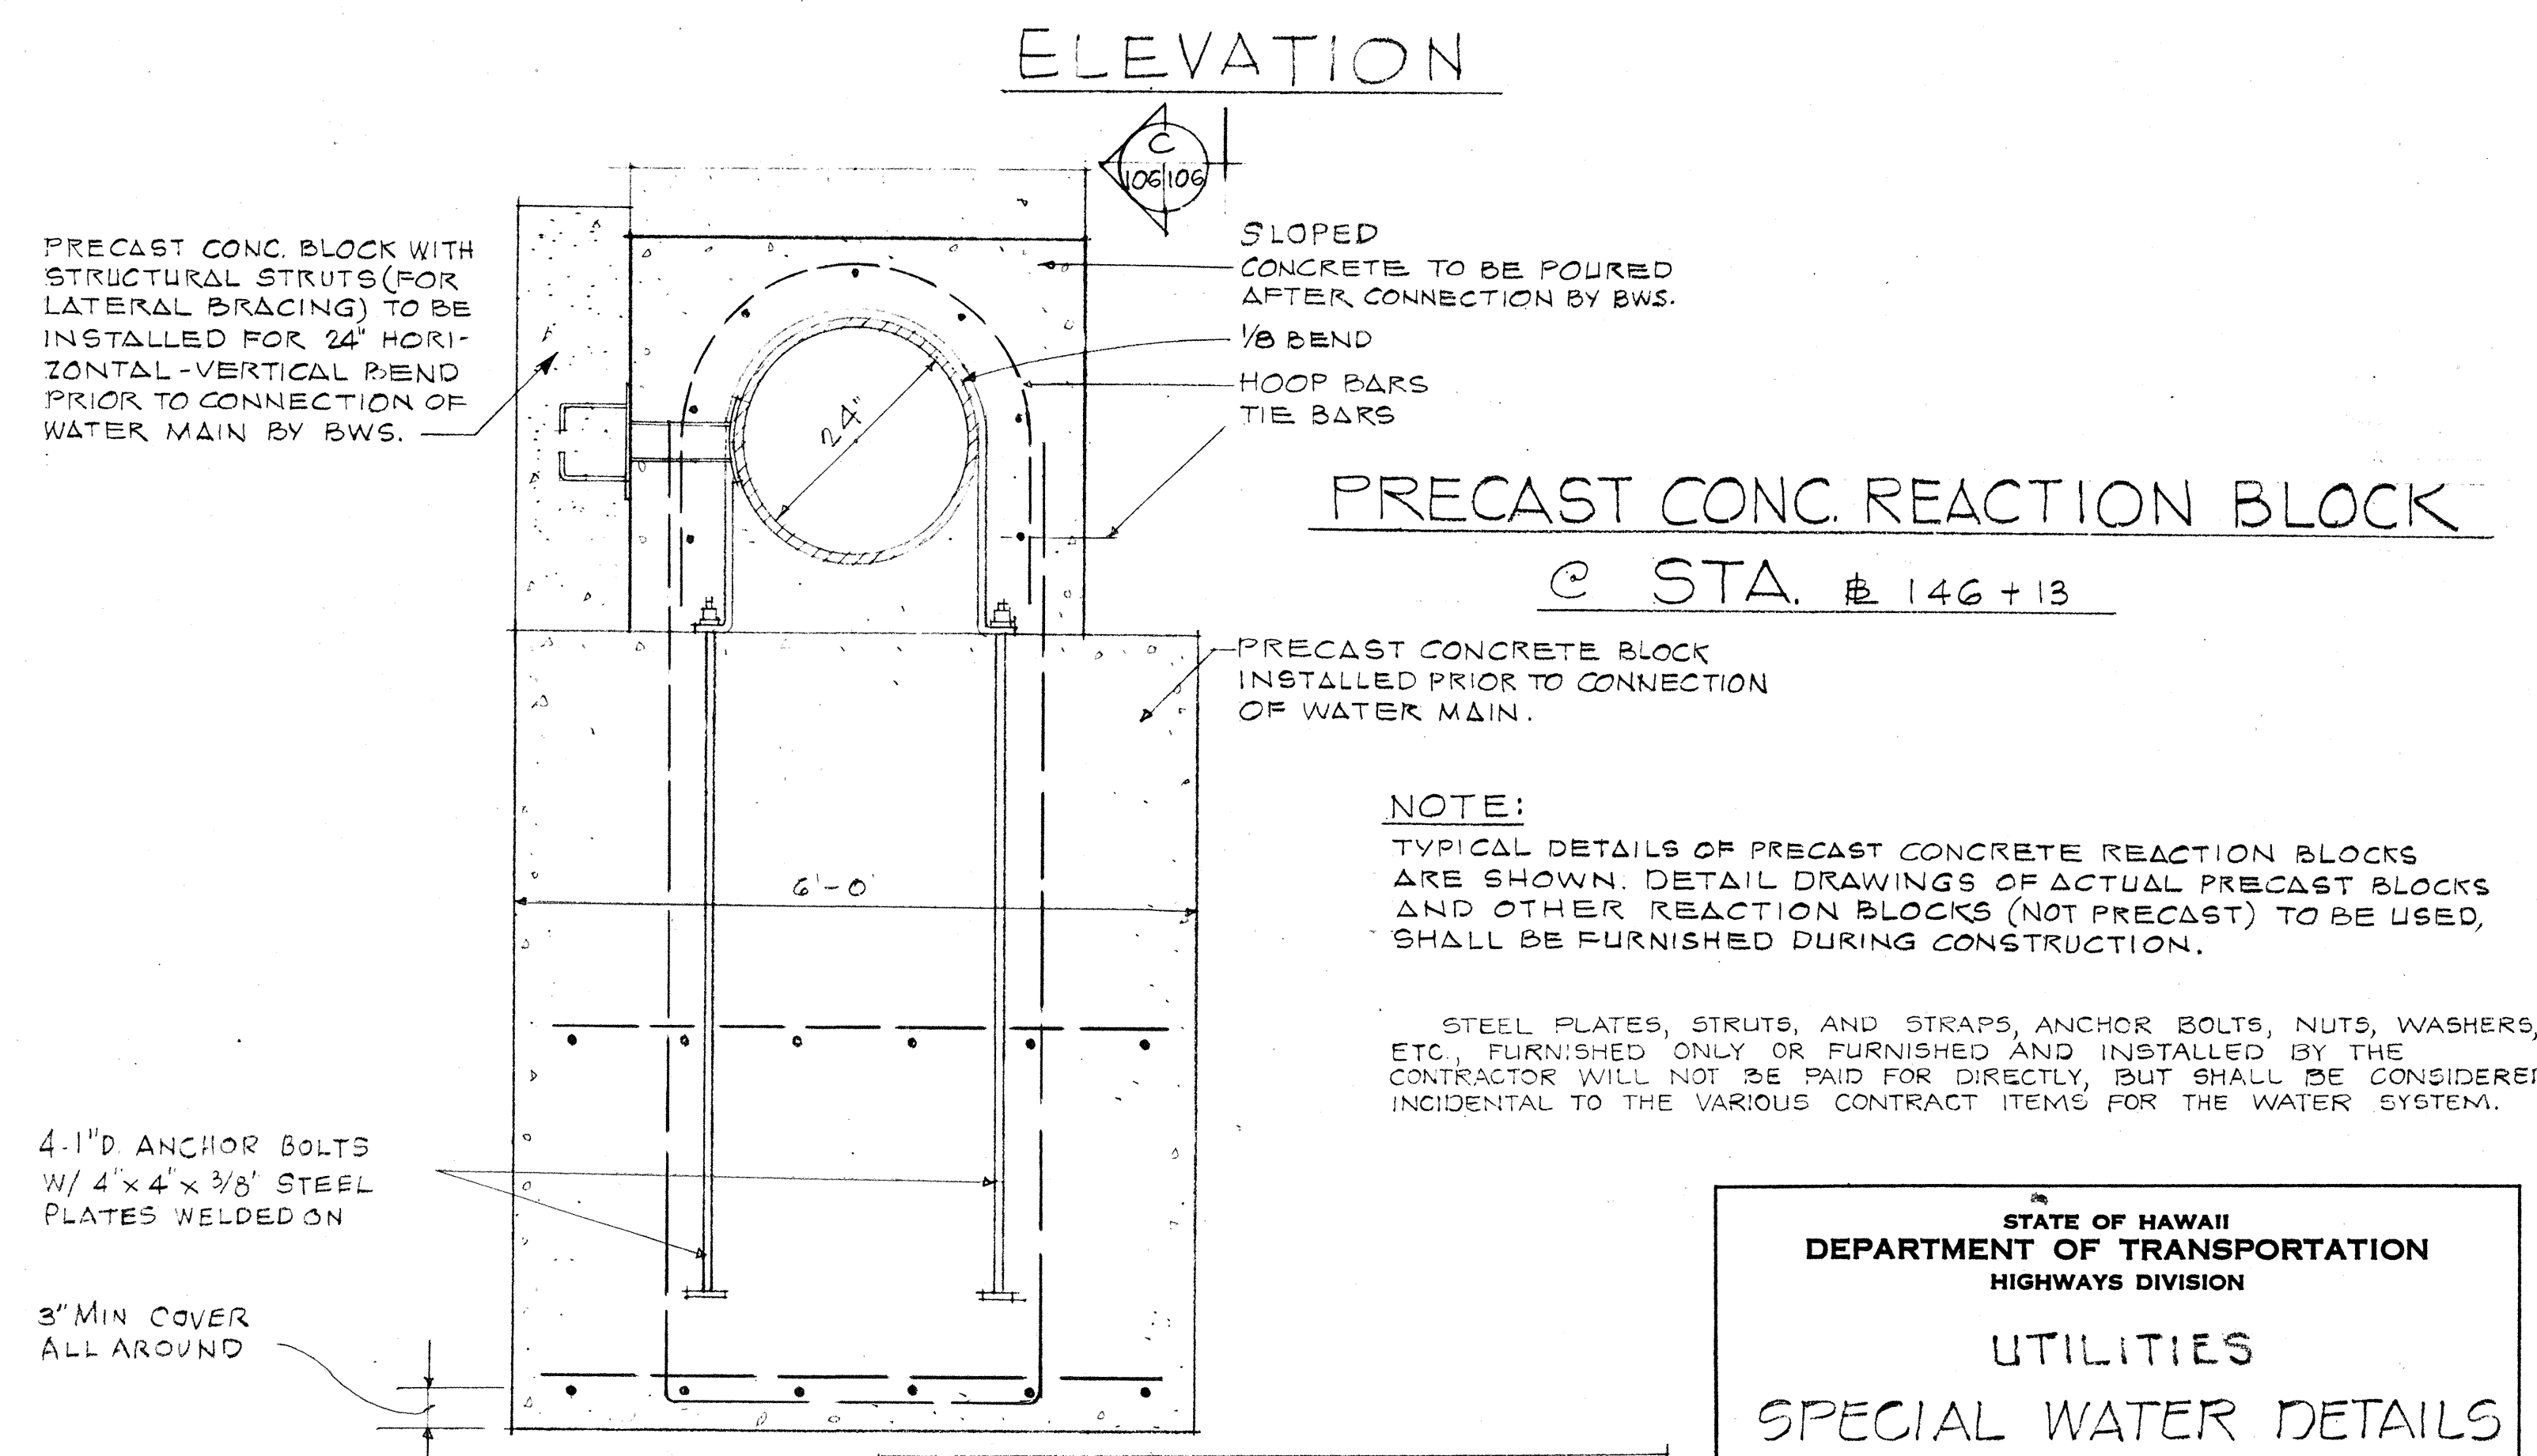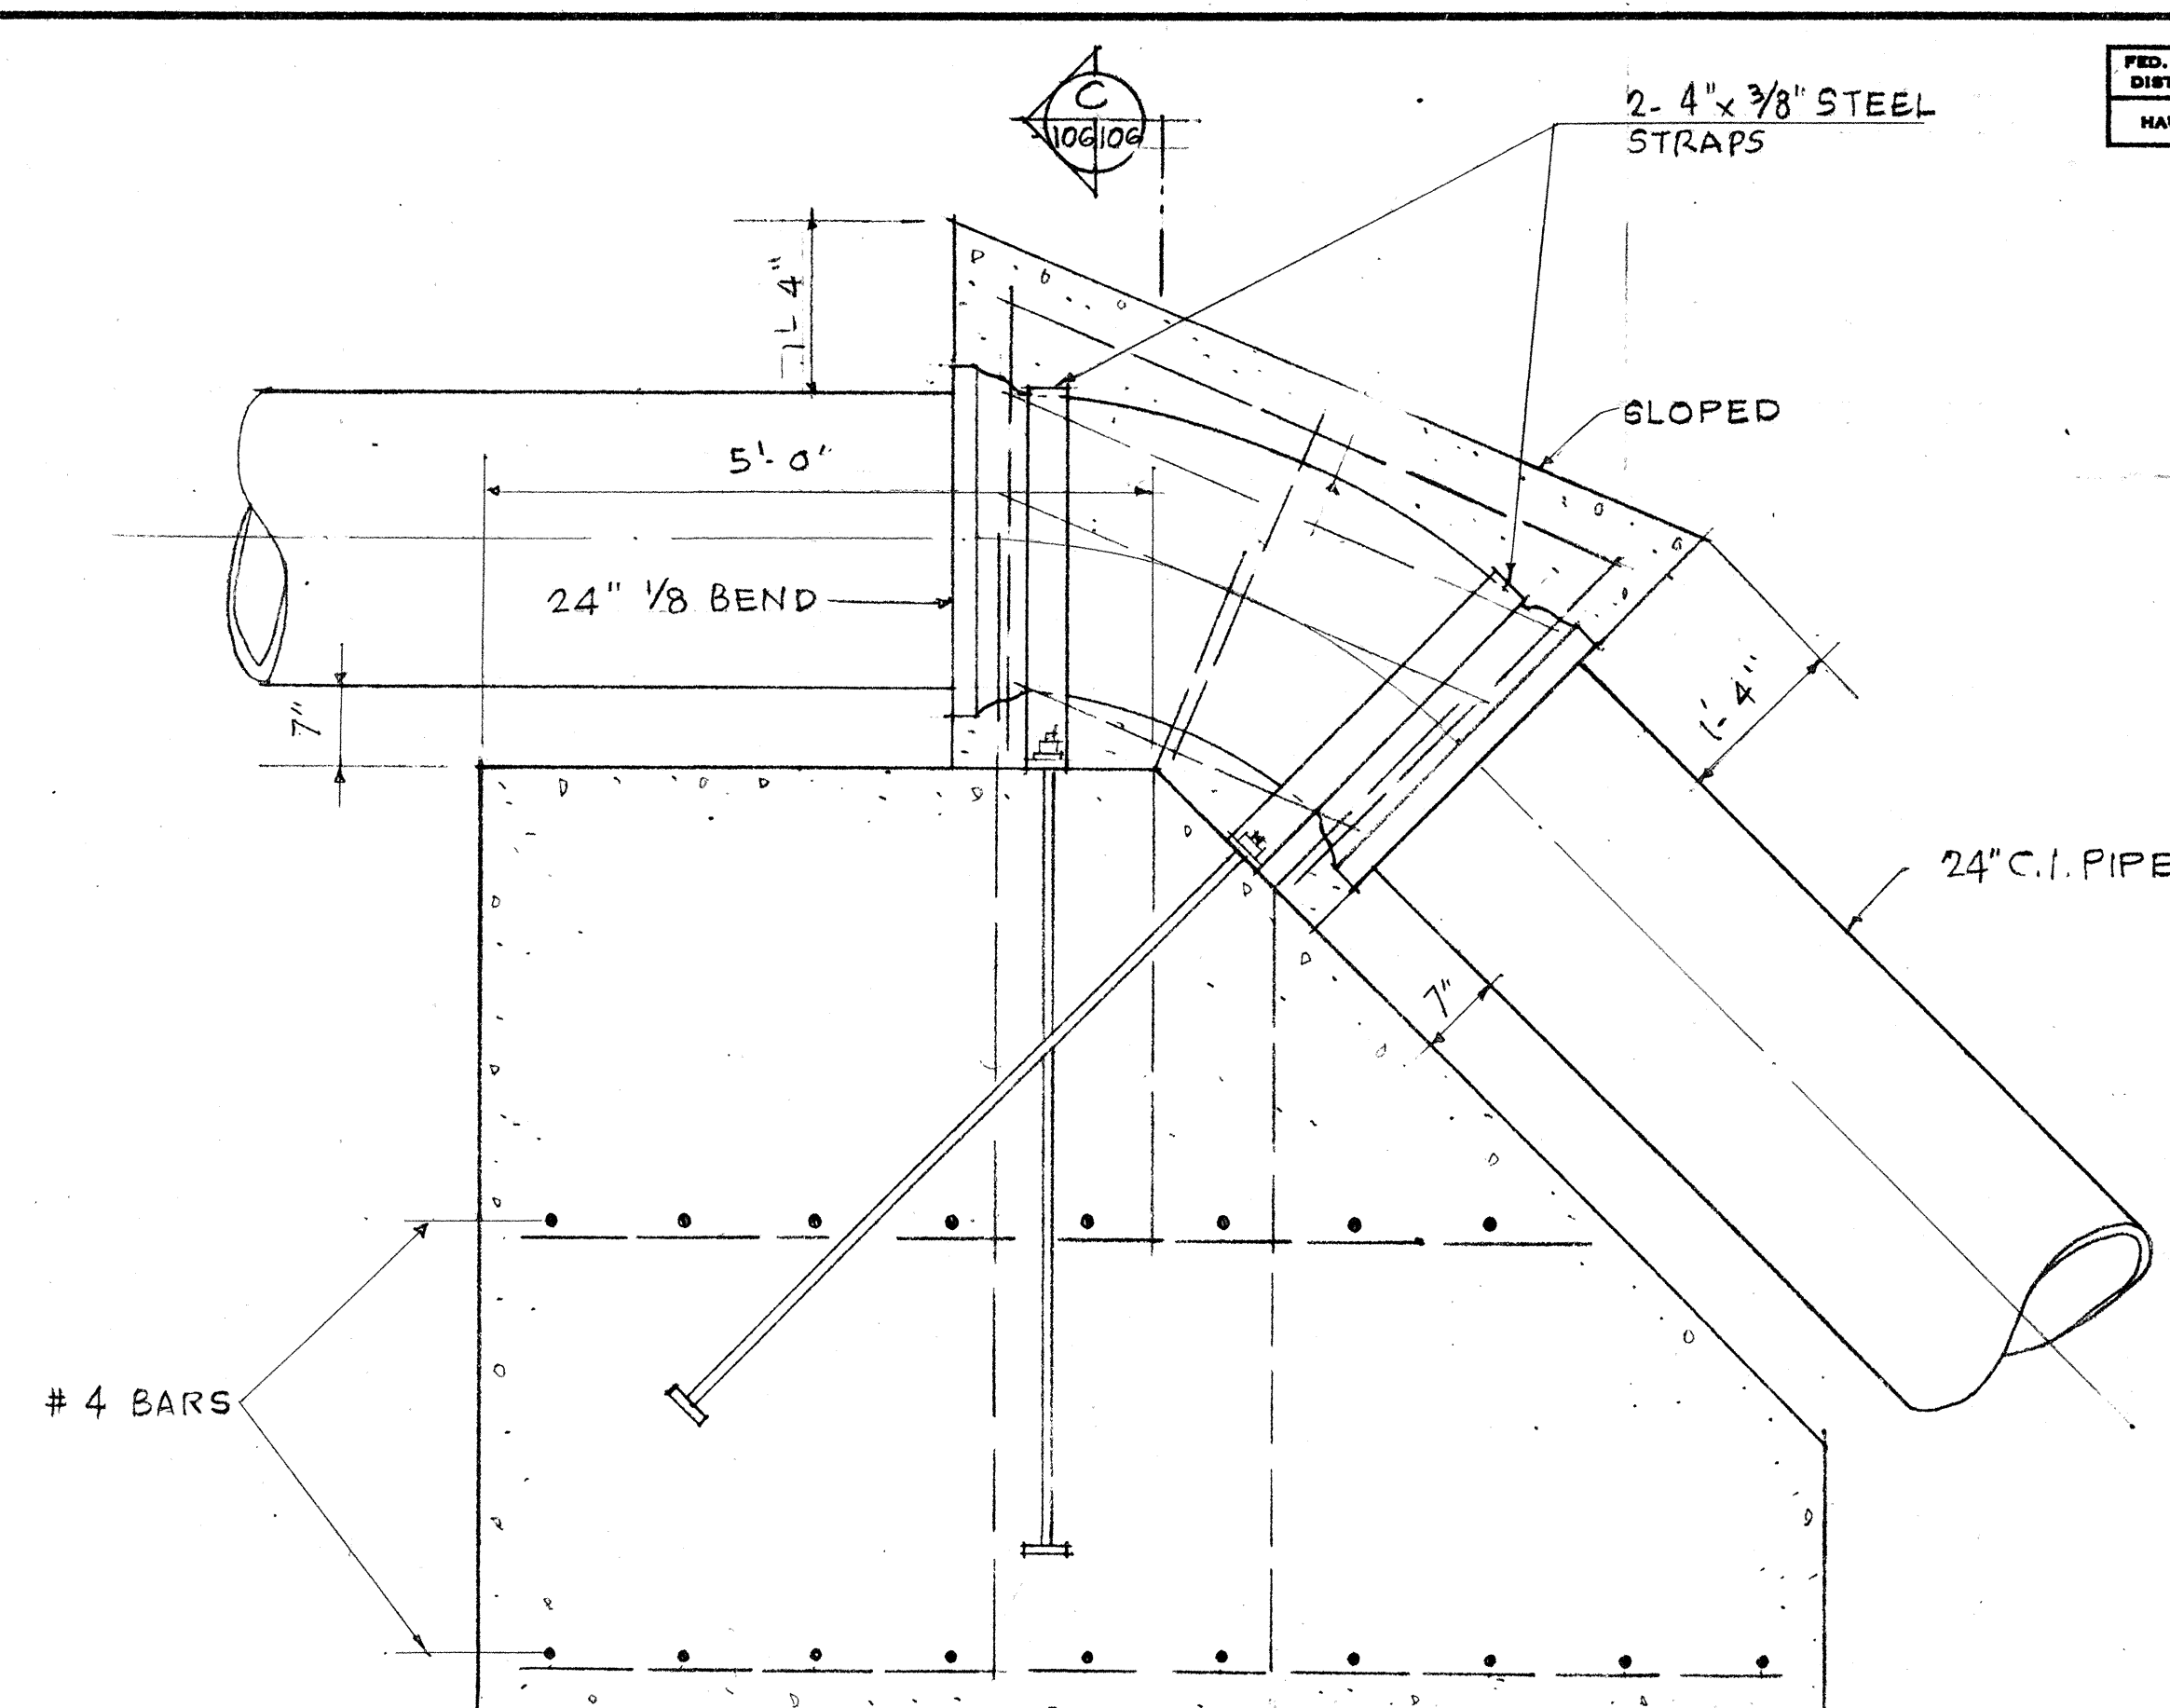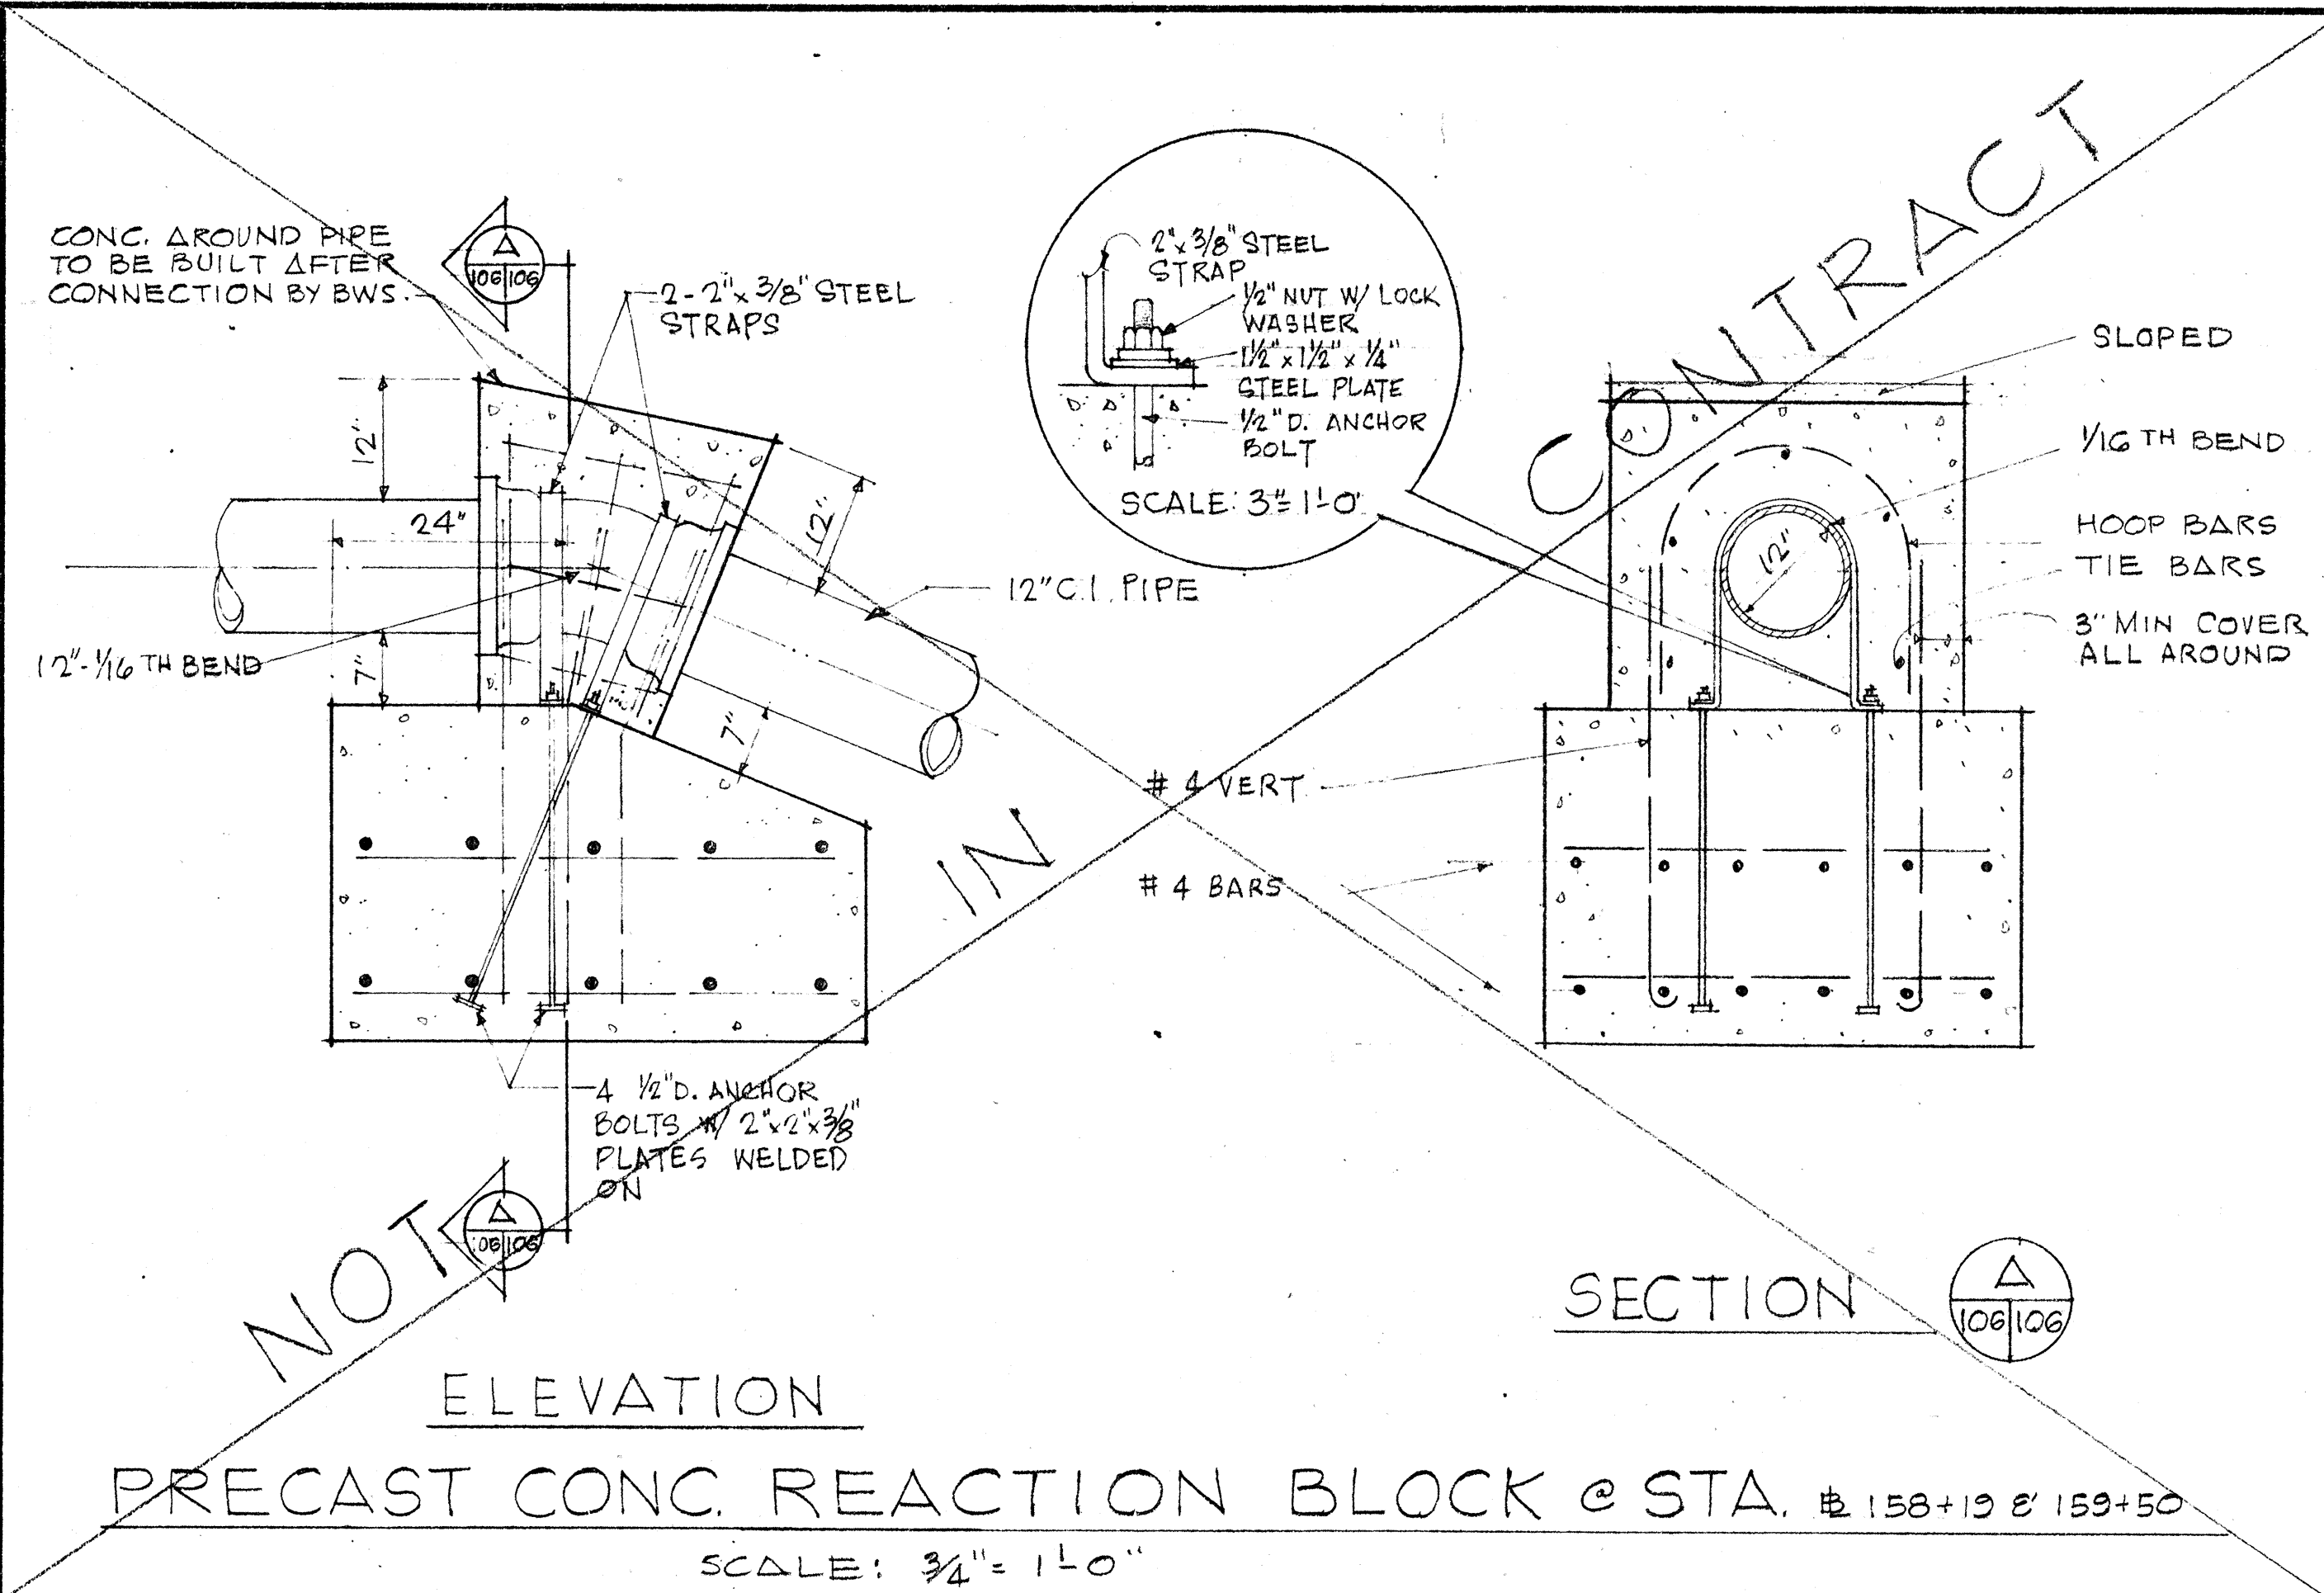

WILSON, CRANDOLPH, ORA, INC.
PARK ASSOCIATES, INC.
ARCHITECTS & ENGINEERS

SECT. C
SC: 3/4" = 1'-0"

APPROVED
Assistant Chief Engineer, BWS

2-8-66
DATE

STATE OF HAWAII
DEPARTMENT OF TRANSPORTATION
HIGHWAYS DIVISION
UTILITIES
SPECIAL WATER DETAILS
INTERSTATE HIGHWAY (LUNALILO FREEWAY)
FAI PROJ. NO. I-HI-1(6) UNIT 2
SCALE: 3/4" = 1'-0"
DATE: NOVEMBER, 1966
SHEET No. 7 OF 13 SHEETS


83

FED. AID DIST. NO.	STATE	FED. AID PROJ. NO.	FISCAL YEAR	SHEET NO.	TOTAL SHEETS
HAWAII	HAWAII	I-HI-1(6) Unit 2	1966	85	209


SCHEDULE OF COPPER FITTINGS
(SOLDERED JOINT)

ITEM NO.	DESCRIPTION	SINGLE SERVICE CONN.	MULTIPLE SERV.CONN.	
		TWO SERVICES	THREE SERVICES	
1	Corporation Stop Brass (H-10003)	1	1	1
2	Ground Joint Union (Style Copper To N.P.T.E. No. C-109)	1	1	1
3	Adapter, Copper To N.P.T.E. (Style No. C-101)	2	1	1
4	Stopcock Brass(BWS Standard)	1	1	1
5	Fitting Adapter, (Style Fitting To N.P.T.E. No. C-104)	—	1	1
6	Tee, Copper To Copper To Copper (Style No. T- 300)	—	1	1
7	Bushings, Fitting To Copper (Style No. C-103)	—	2	2
8	90° Elbow, Copper To Copper (Style No. C-200)	—	2	2
9	Adapter, Copper To N.P.T.E. (Style No. C-101)	1	2	3
10	Stopcock Brass(BWS. Standard)	1	2	3
11	Reducing Tee, Copper To Copper To Copper(Substitute For Items Number 6 and 7). (Style No. T- 300)	—	1	1
12	Tee, Copper To Copper To Copper (Style No. T- 300)	—	—	1
13	Bushing, Fitting To Copper (Style No. C-103)	—	—	1
14	Reducing Tee, Copper To Copper To Copper(Substitute For Items Number 12 and 13) (Style No. T- 300)	—	—	1

NOTE:
Reference Numbers shown thus (H-10003) are from Mueller Co. Catalog "H" and (Style No. T-300) are from Mueller Brass Co. "Streamline" Catalog S-354. Approved Equal may be used.

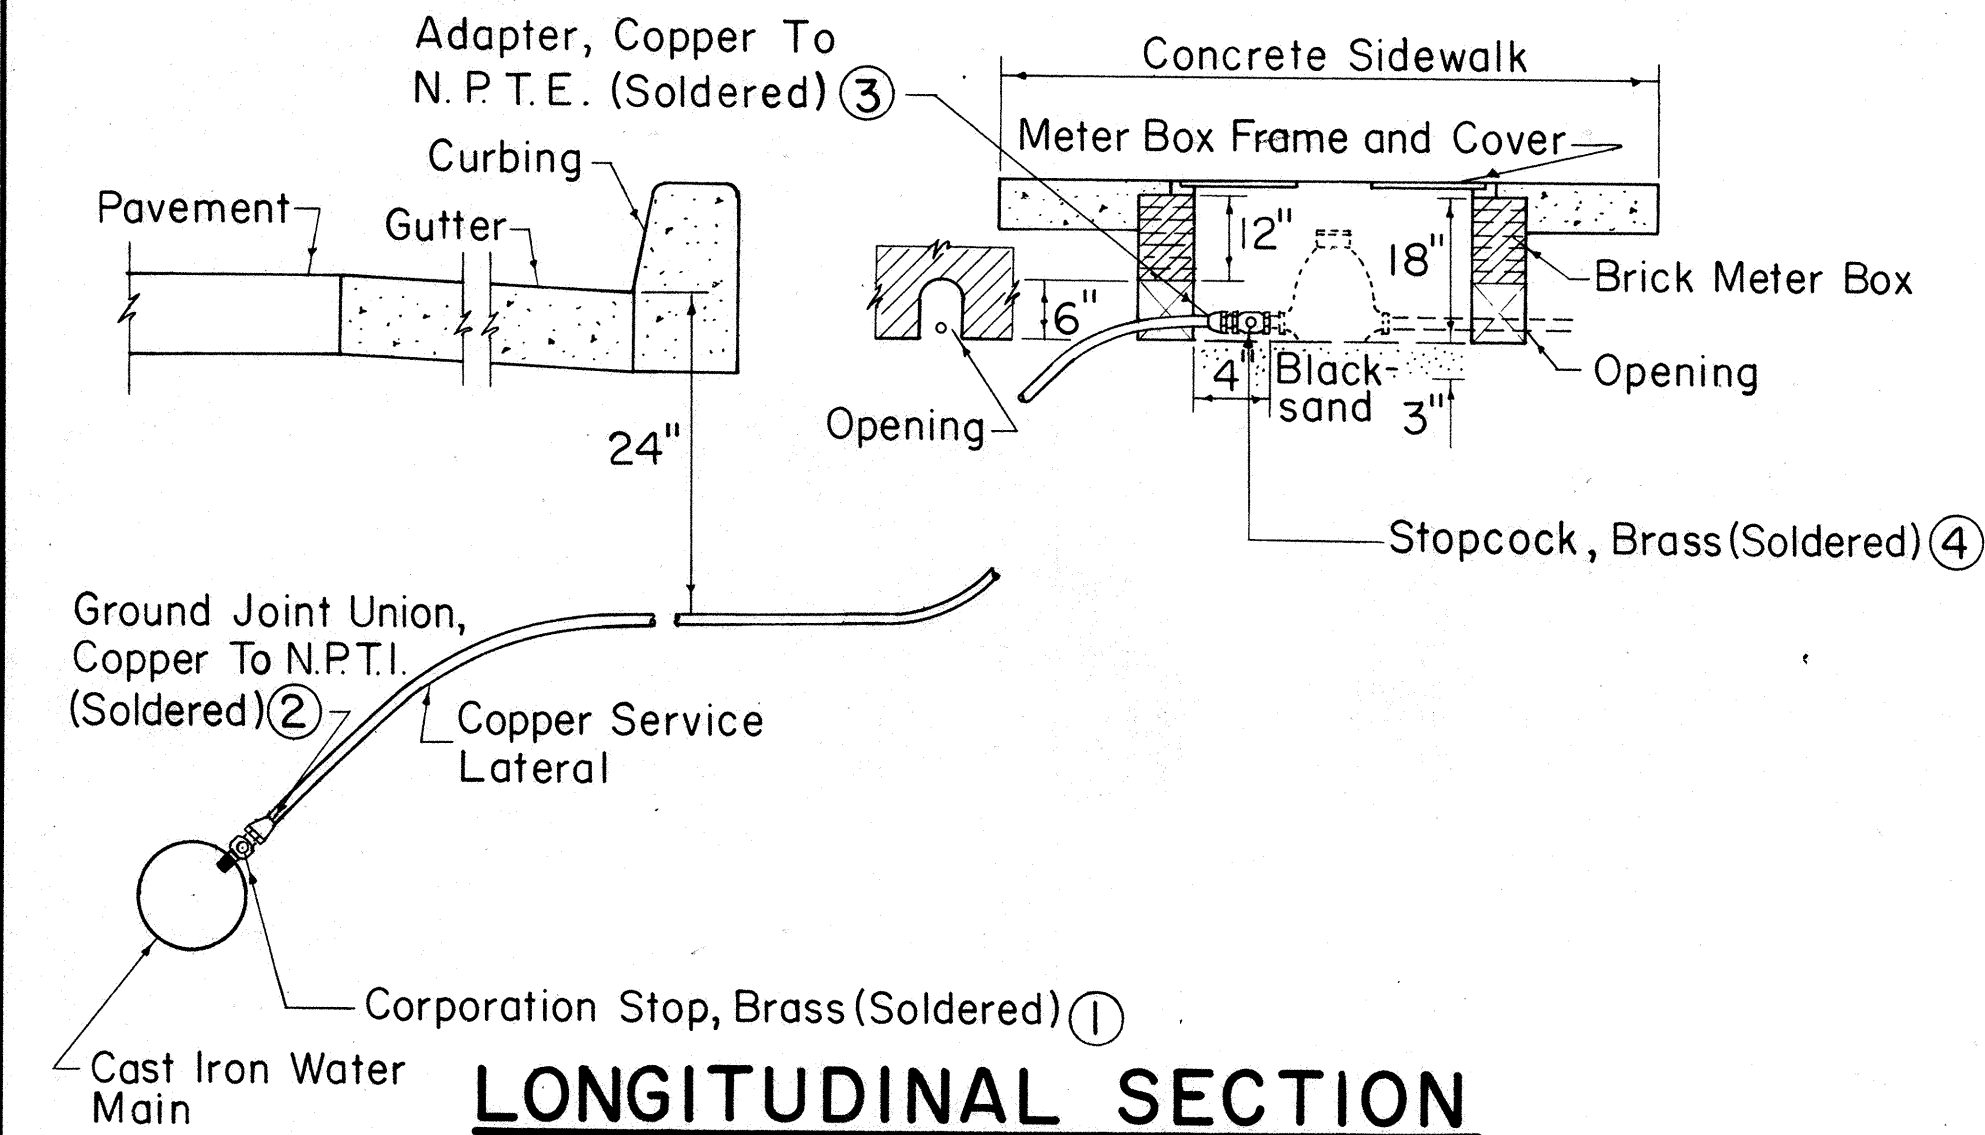


LONGITUDINAL SECTION

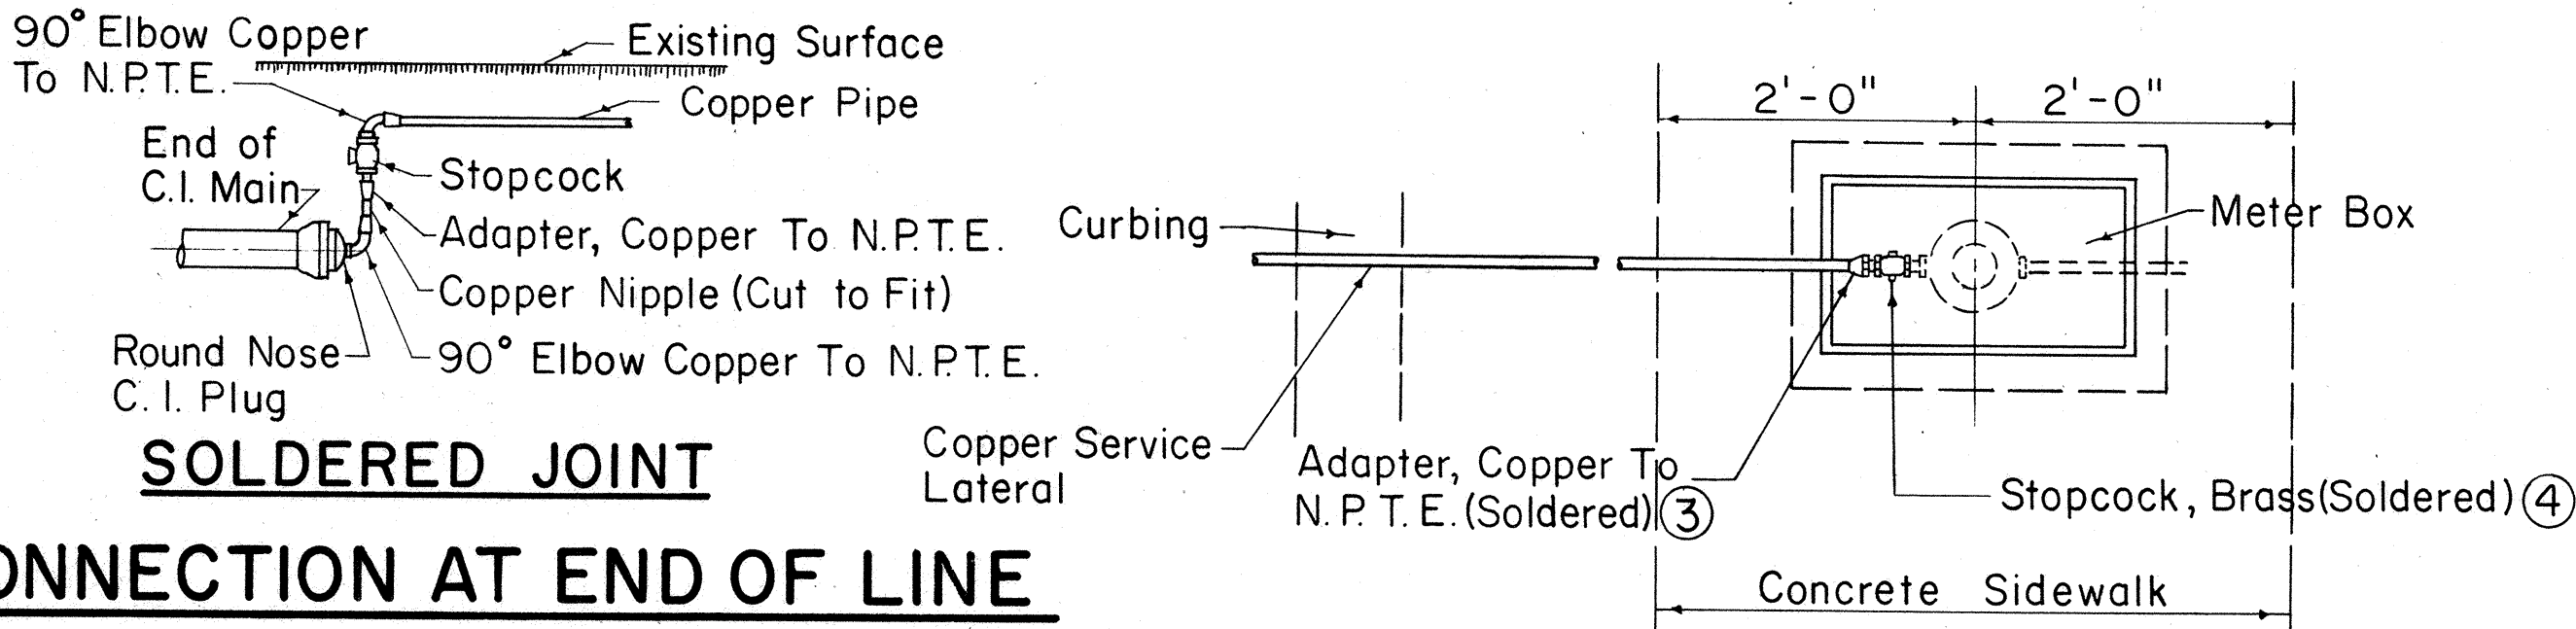


SOLDERED JOINT

SERVICE LATERAL CONNECTION AT END OF LINE

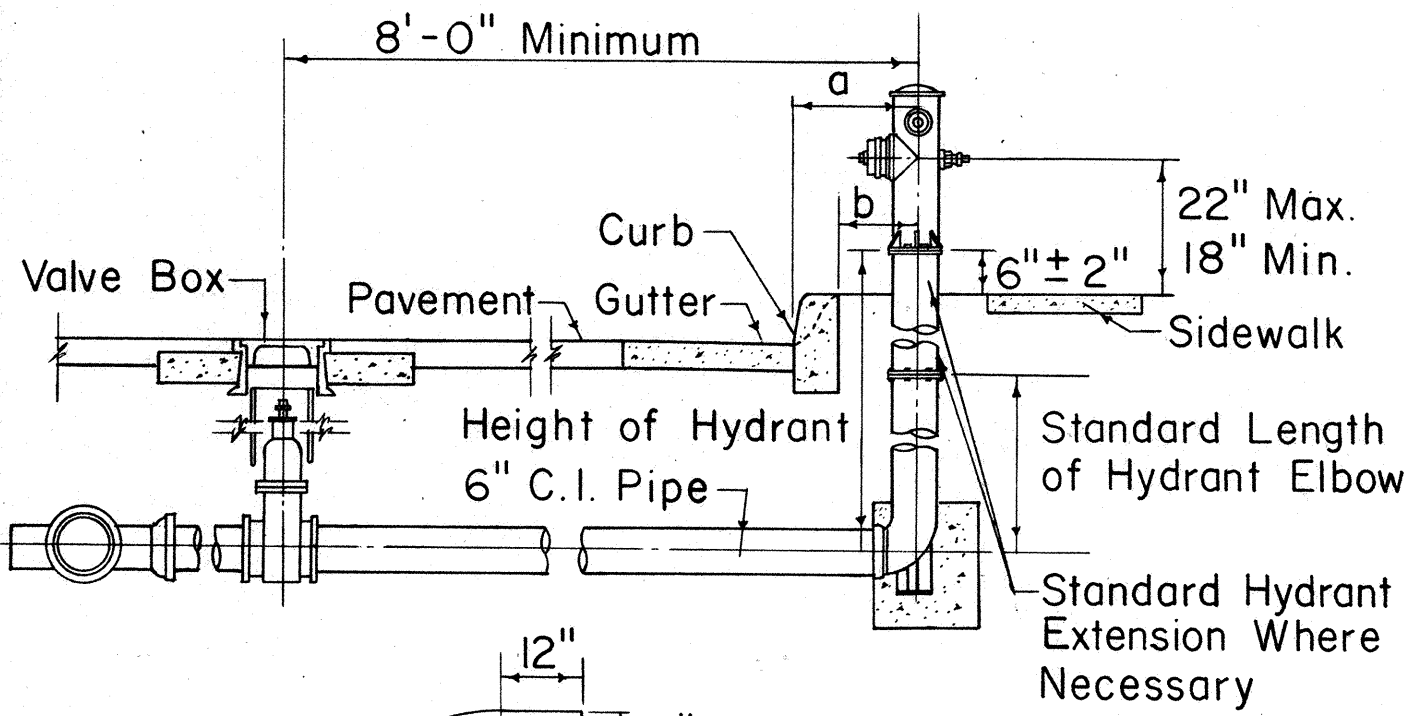

a	20" Min. (Standard Curb)
b	20" Min. (Roll Curb)

NOTE:
Gaskets for flanged joints shall be 1/16 inch duck-inserted rubber packing Garlock No. 19. Bolts shall be 5/8" diameter x 2 3/4" long steel machine bolts with cut threads, American Standard heavy hexagon heads, galvanized. Nuts shall be American Standard heavy cold punched hexagon nuts, galvanized.

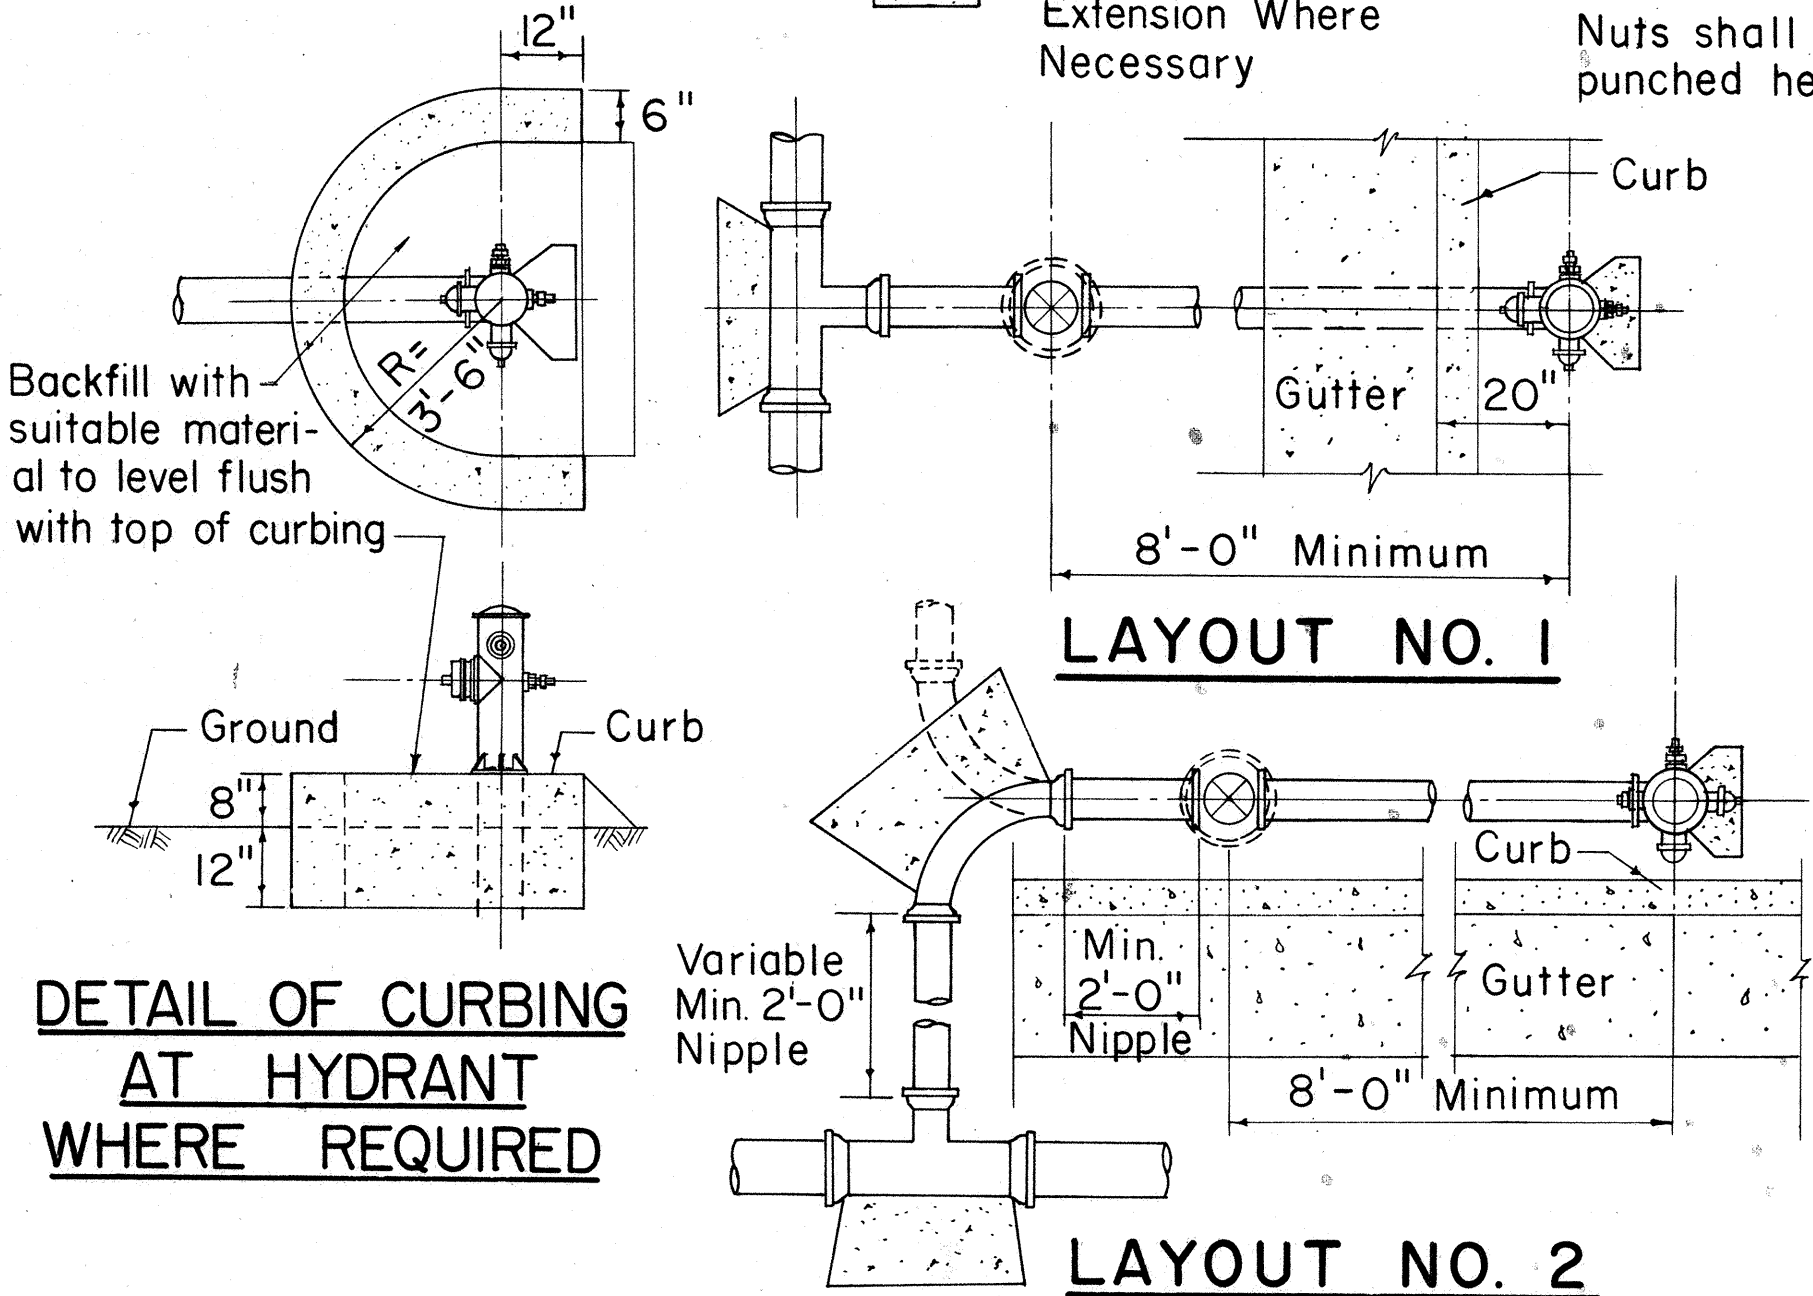


DETAIL OF CURBING
AT HYDRANT
WHERE REQUIRED

LAYOUT NO. 2

STANDARD FIRE HYDRANT LAYOUT

SINGLE SERVICE CONNECTION

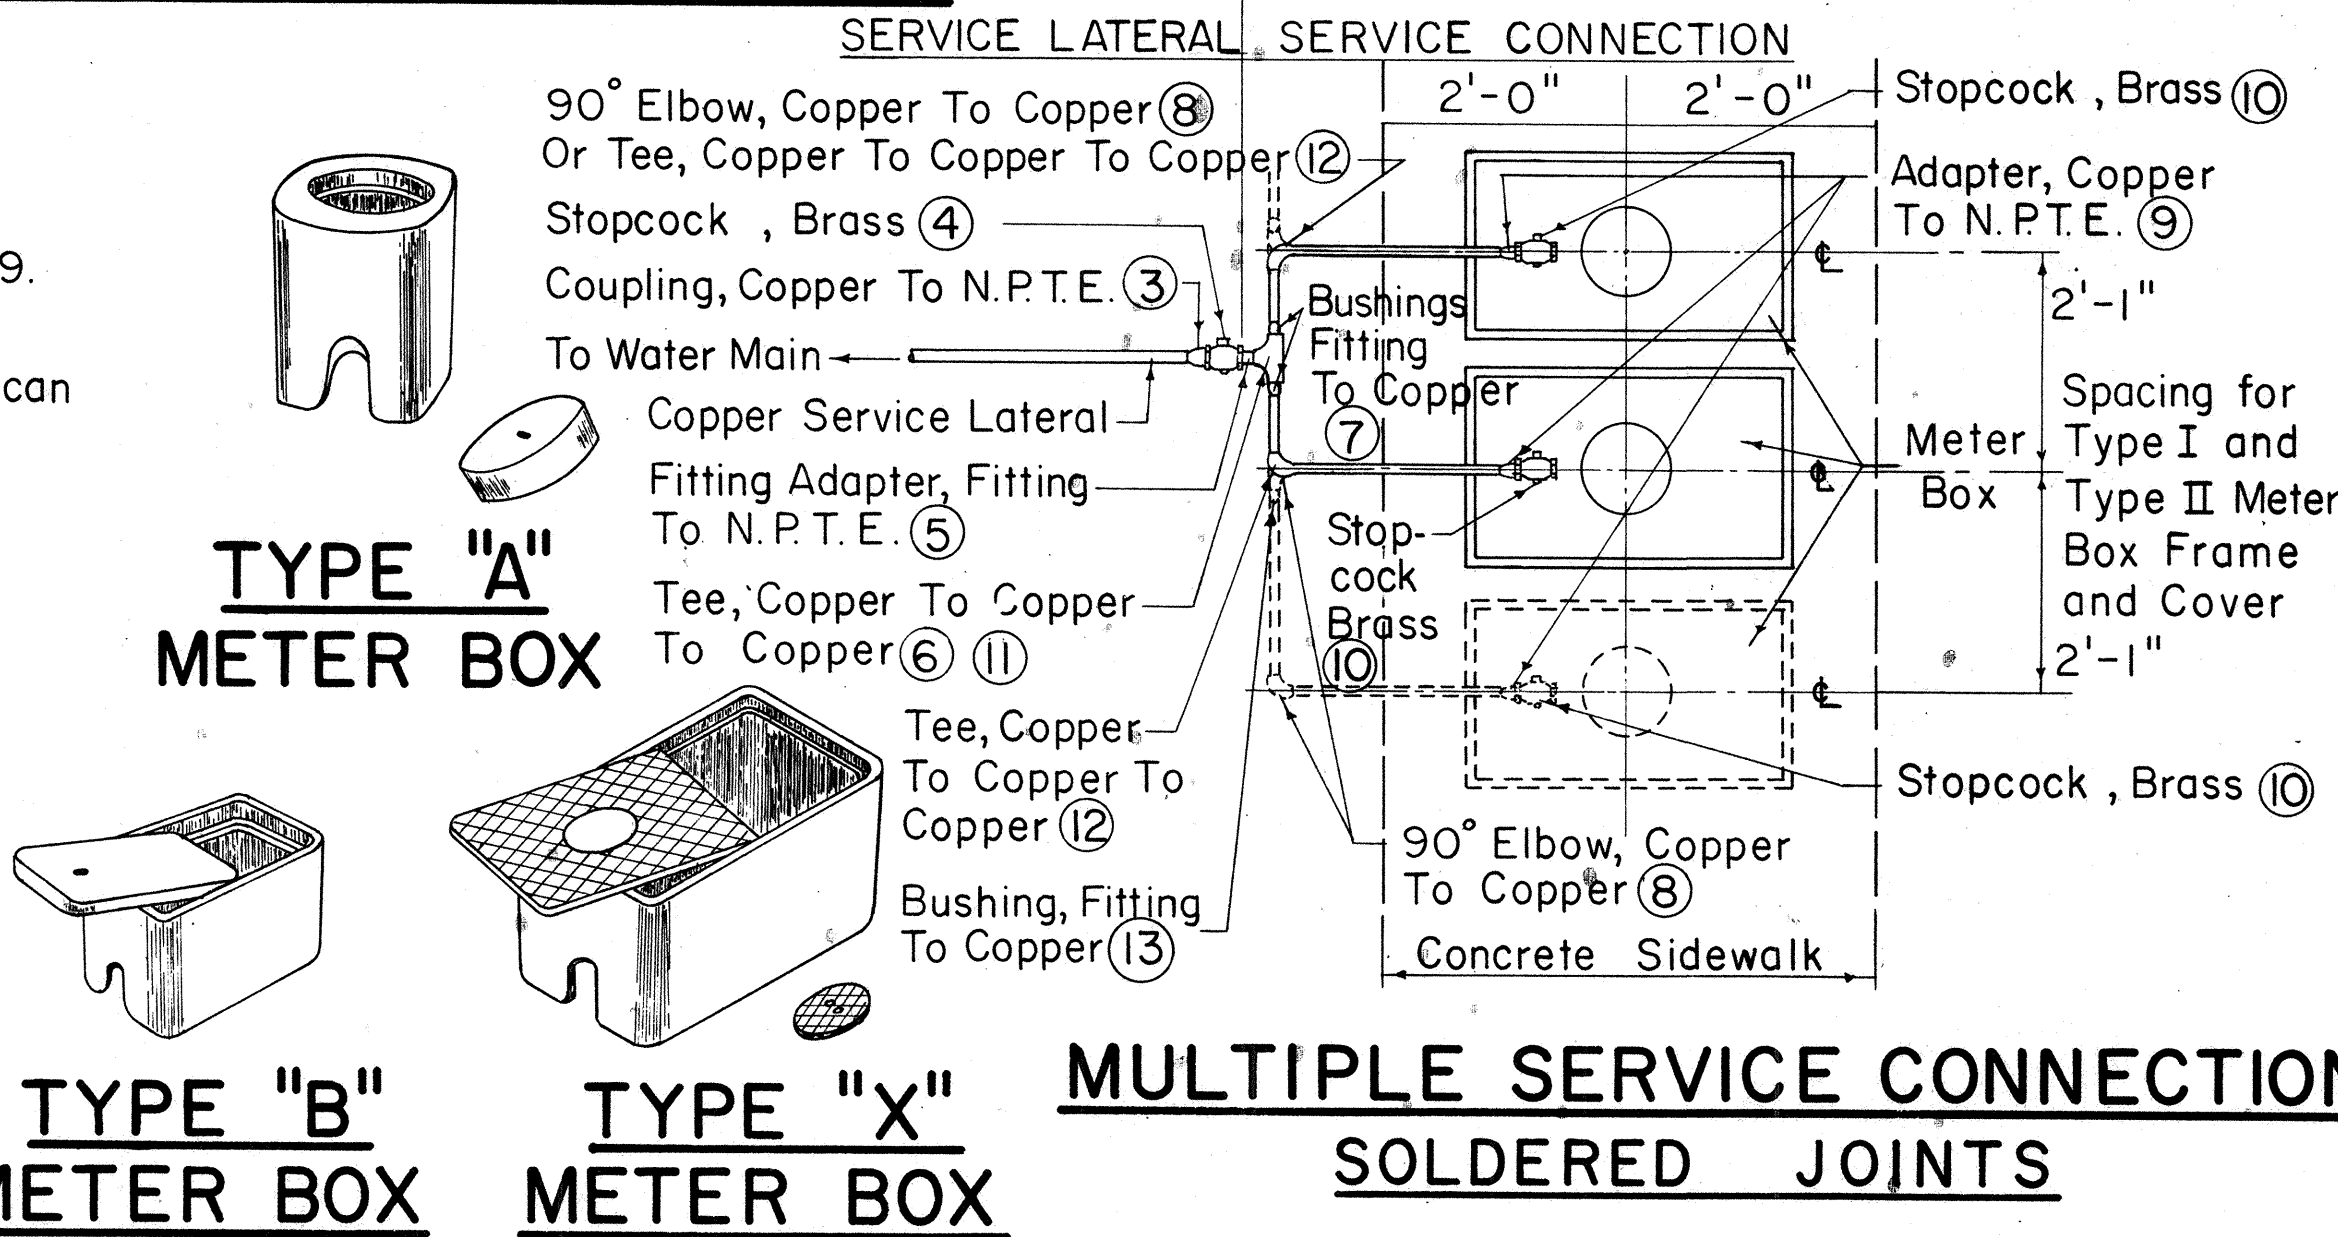

TYPE "A"
METER BOX

TYPE "B"
METER BOX

TYPE "X"
METER BOX

MULTIPLE SERVICE CONNECTION
SOLDERED JOINTS

STANDARD LENGTHS FOR HYDRANT ELBOWS	
	30"
	36"
	42"
	48"

Standard Hydrant Extensions are available in the following Lengths:
6 to 30 inches long in increments of 6 inches

METER BOX DATA					
TYPE METER BOX	METER SIZES	OVERALL DIMENSIONS AT BOTTOM	OVERALL DIMENSIONS AT TOP	COMPLETE WEIGHT	OVERALL DIMENSIONS OF LID
A	5/8" or 3/4" Without Valve	7 1/4" x 7 1/4"	10" x 10"	45 lbs.	7 3/8" Dia.
B	5/8" or 3/4"	9 1/2" x 16"	12 1/4" x 18 3/8"	82 lbs.	8 3/4" x 14 1/2"
X		14 1/2" x 23 1/2"	16" x 25"	143 lbs.	13 1/8" x 22 1/8"

APPROVED:


W. K. K. K.
ASSISTANT CHIEF ENGINEER
BOARD OF WATER SUPPLY
DATE 2-8-66

WILSON, OKAMOTO, OKA, INC.
PARK ASSOCIATES, INC.
ARCHITECTS & ENGINEERS


STATE OF HAWAII
DEPARTMENT OF TRANSPORTATION
HIGHWAYS DIVISION
BOARD OF WATER SUPPLY
CITY & COUNTY OF HONOLULU

STANDARD DETAILS
INTERSTATE HIGHWAY (LUNALILO FRWY)
F.A.I. PROJ. NO. I-HI-1(6) UNIT 2
Not to Scale Date: NOVEMBER, 1965


SHEET NO. 85 OF 133 SHEETS

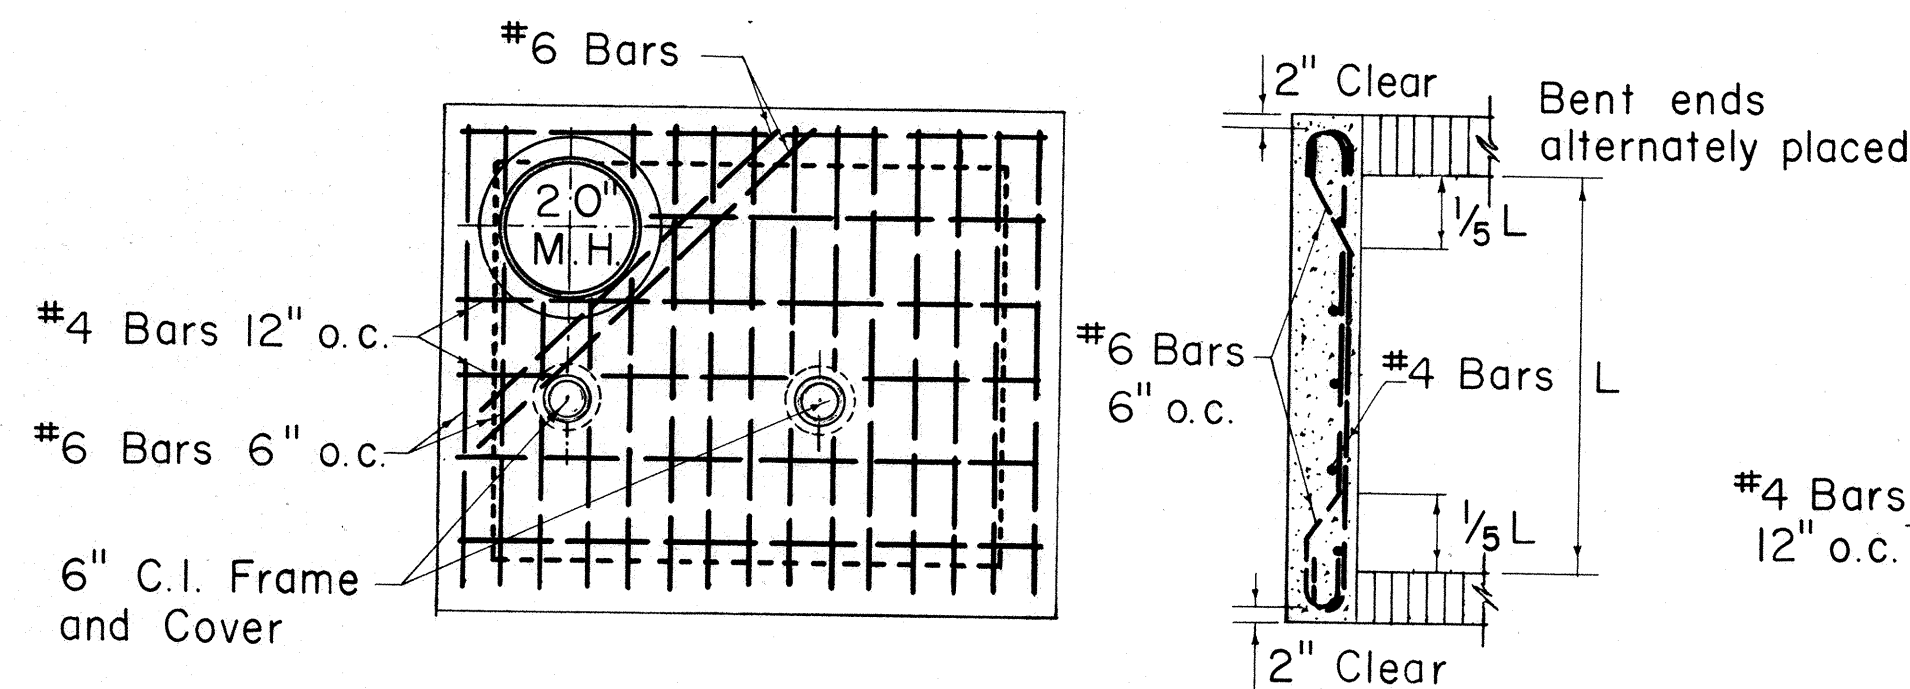




PLAN OF TOP SLAB

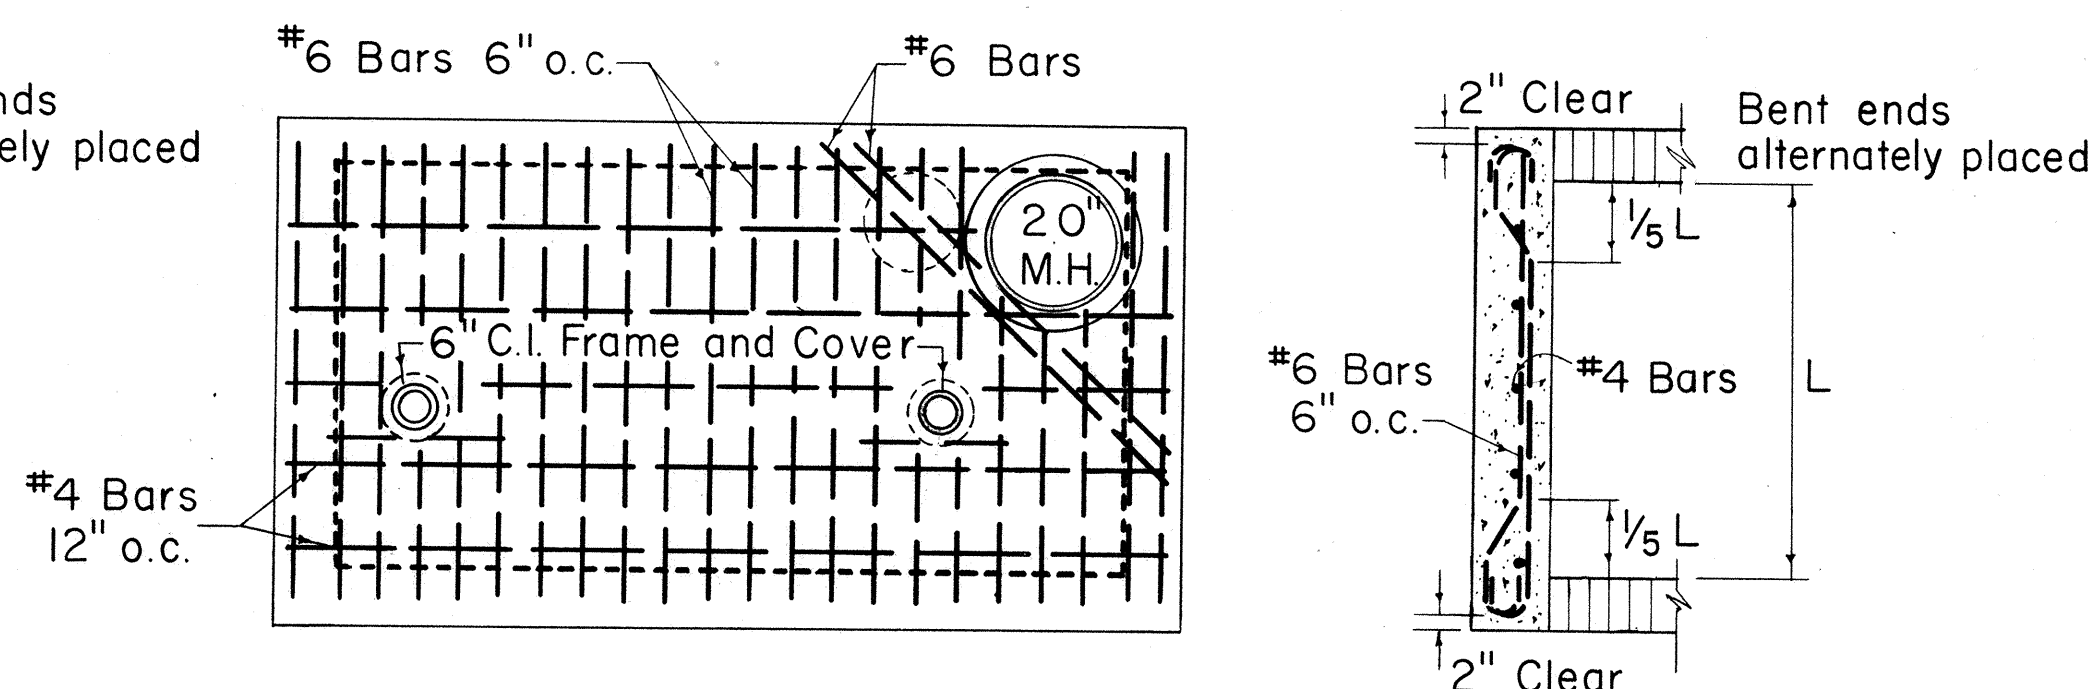

PLAN OF TOP SLAB

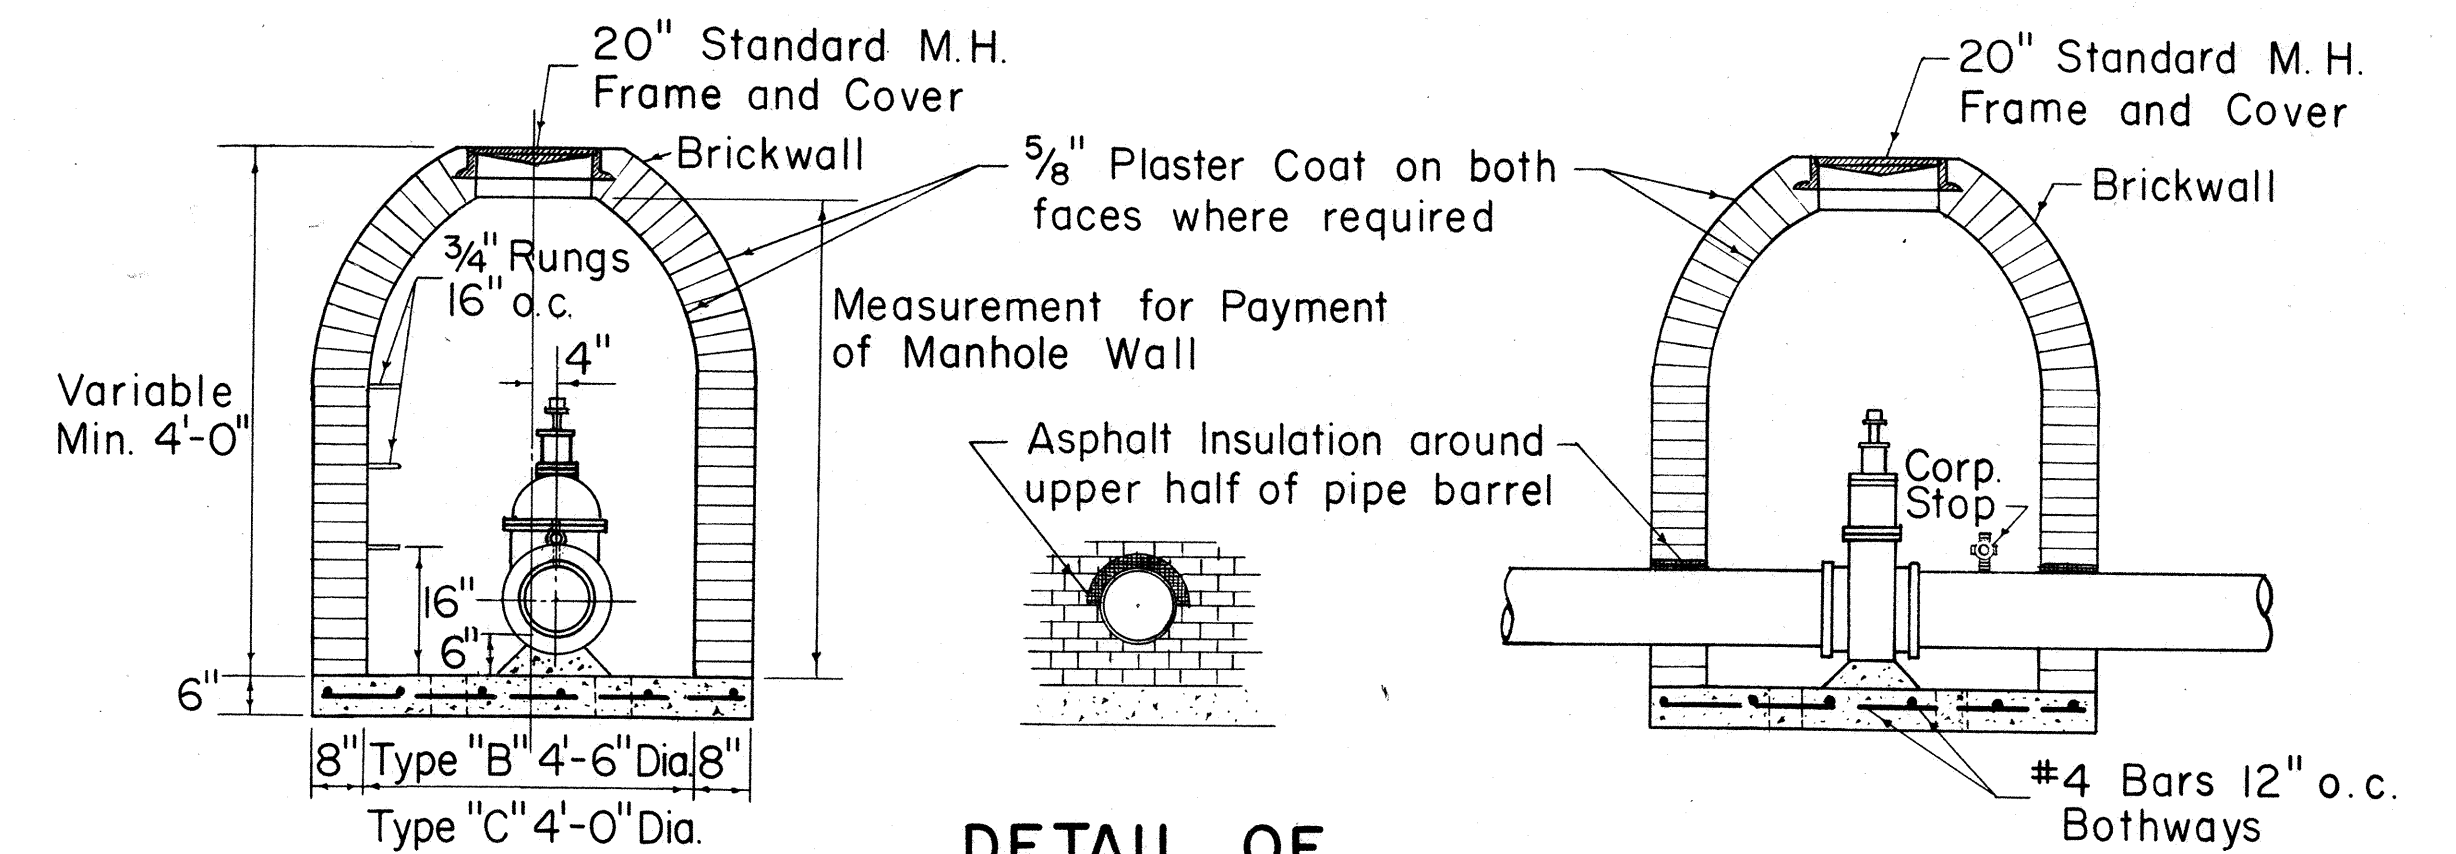


DETAIL OF ASPHALT FILLER

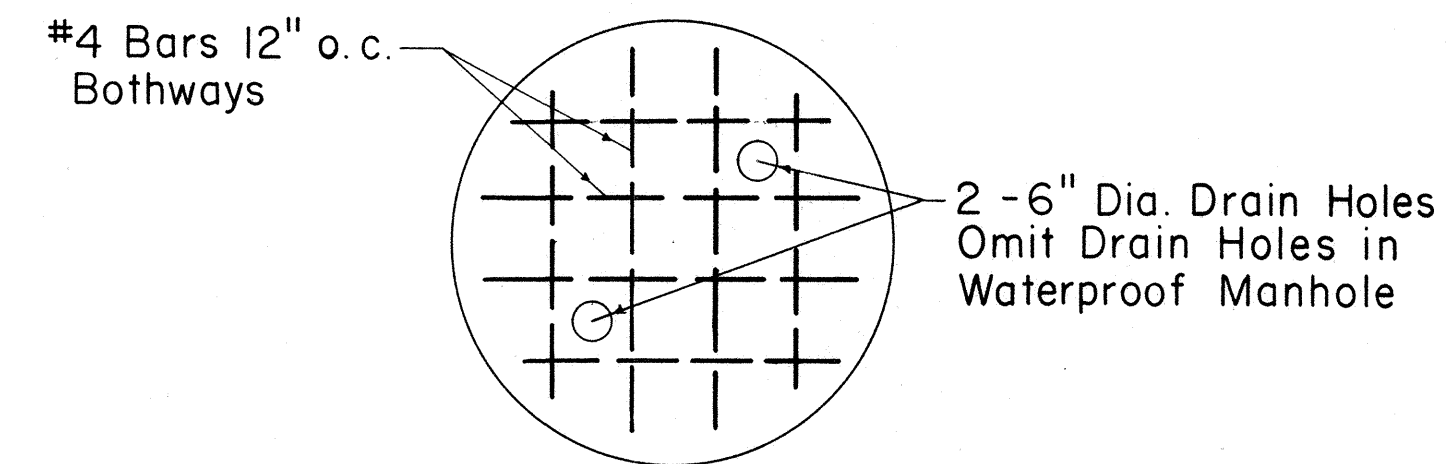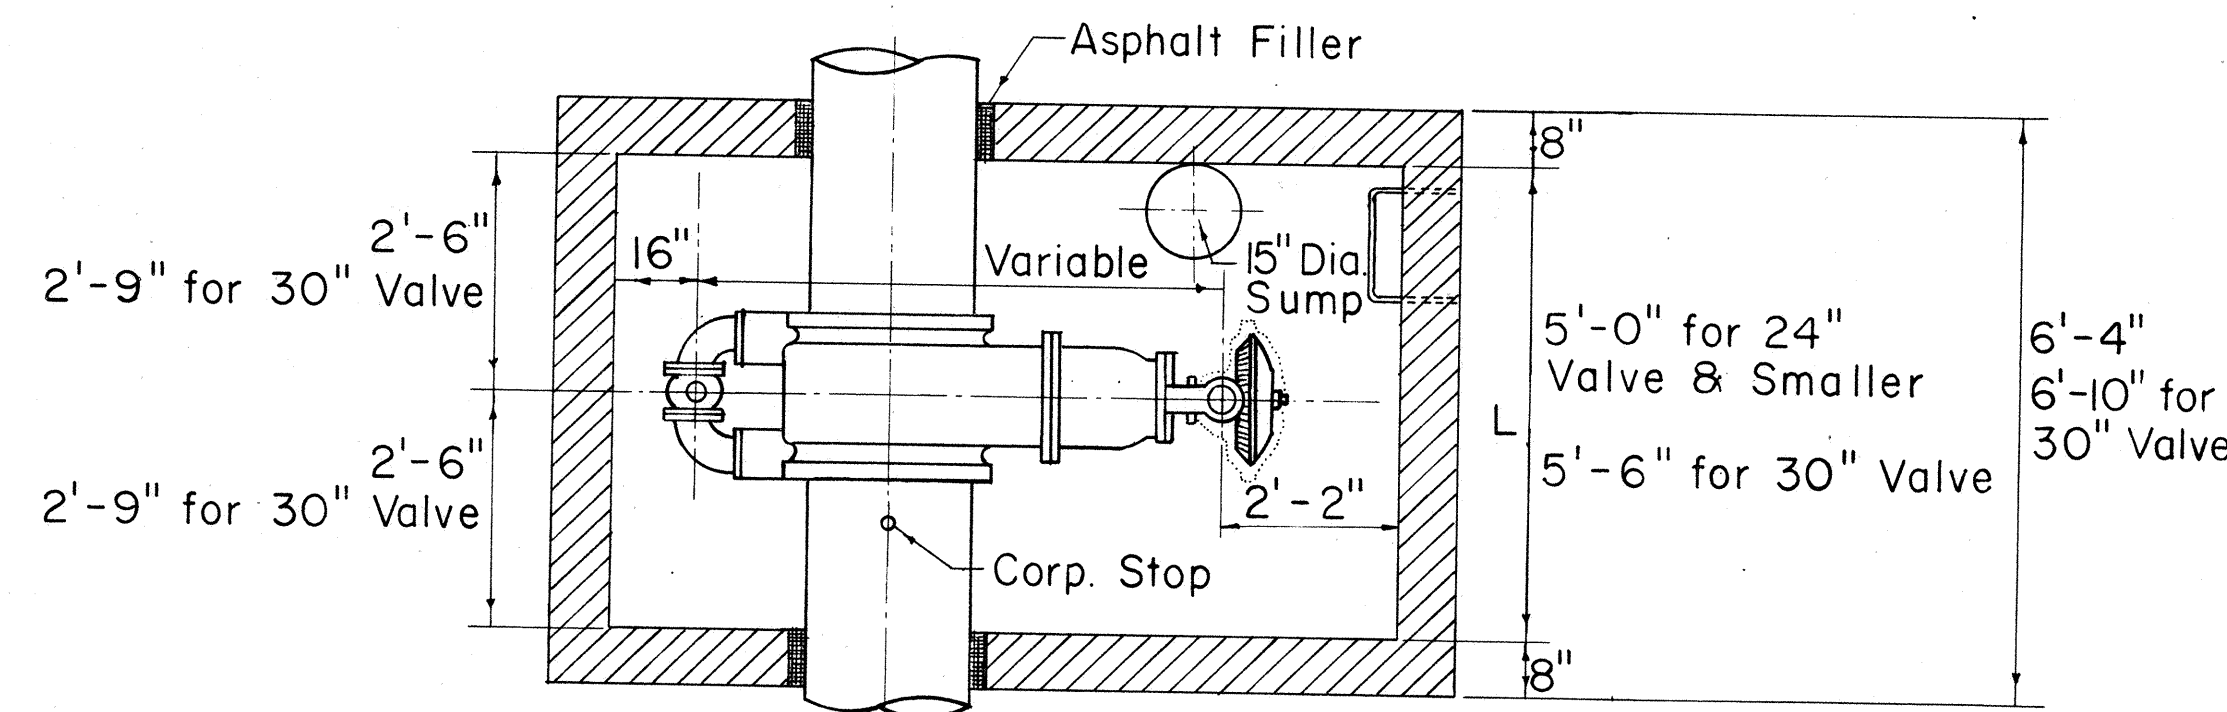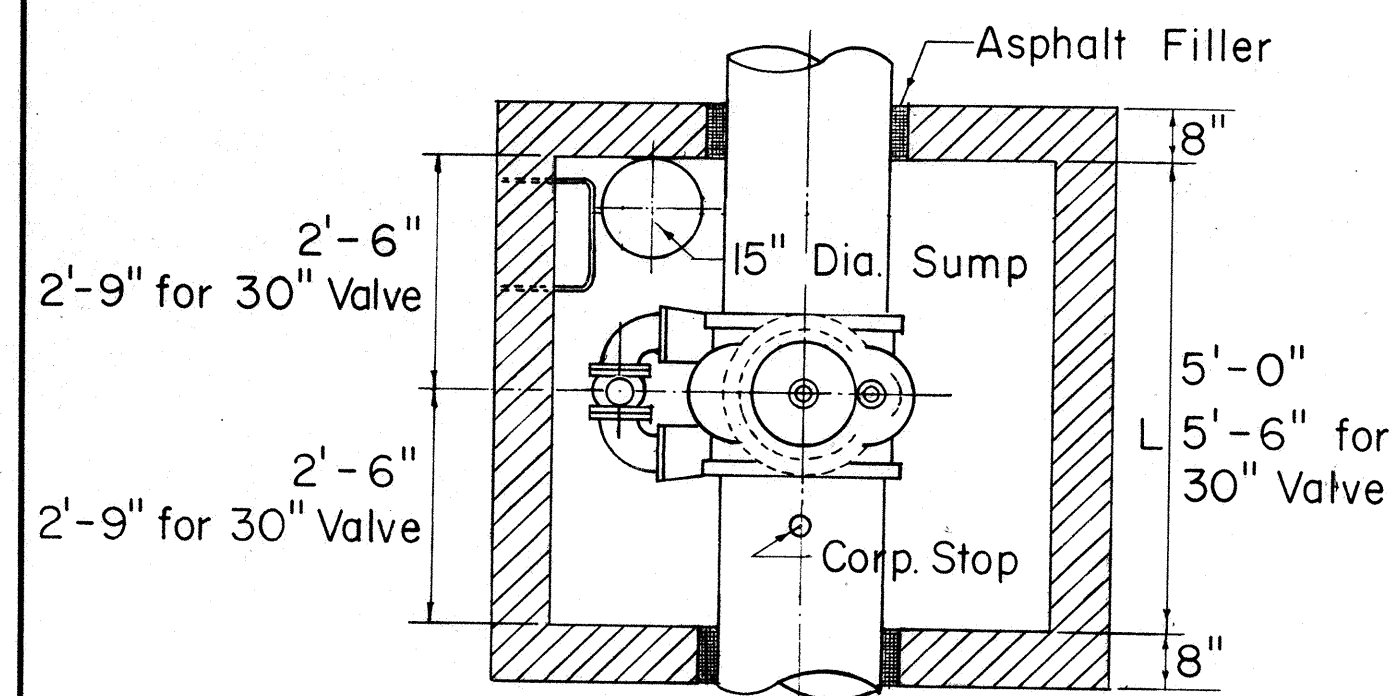


STEEL DETAIL IN BOTTOM SLAB

TABLE "A"
REQUIRED CORPORATION STOP SIZES
AT GATE VALVE

DIA. OF MAIN INCHES	SIZE OF CORP. STOP
4	1" x 1 1/4"
6	1" x 1 1/4"
8	1" x 1 1/4"
12	1" x 1 1/4"
16	1" x 1 1/4"
20	1" x 1 1/4"
24	1 1/2" x 2"
36	1 1/2" x 2"
42	1 1/2" x 2"

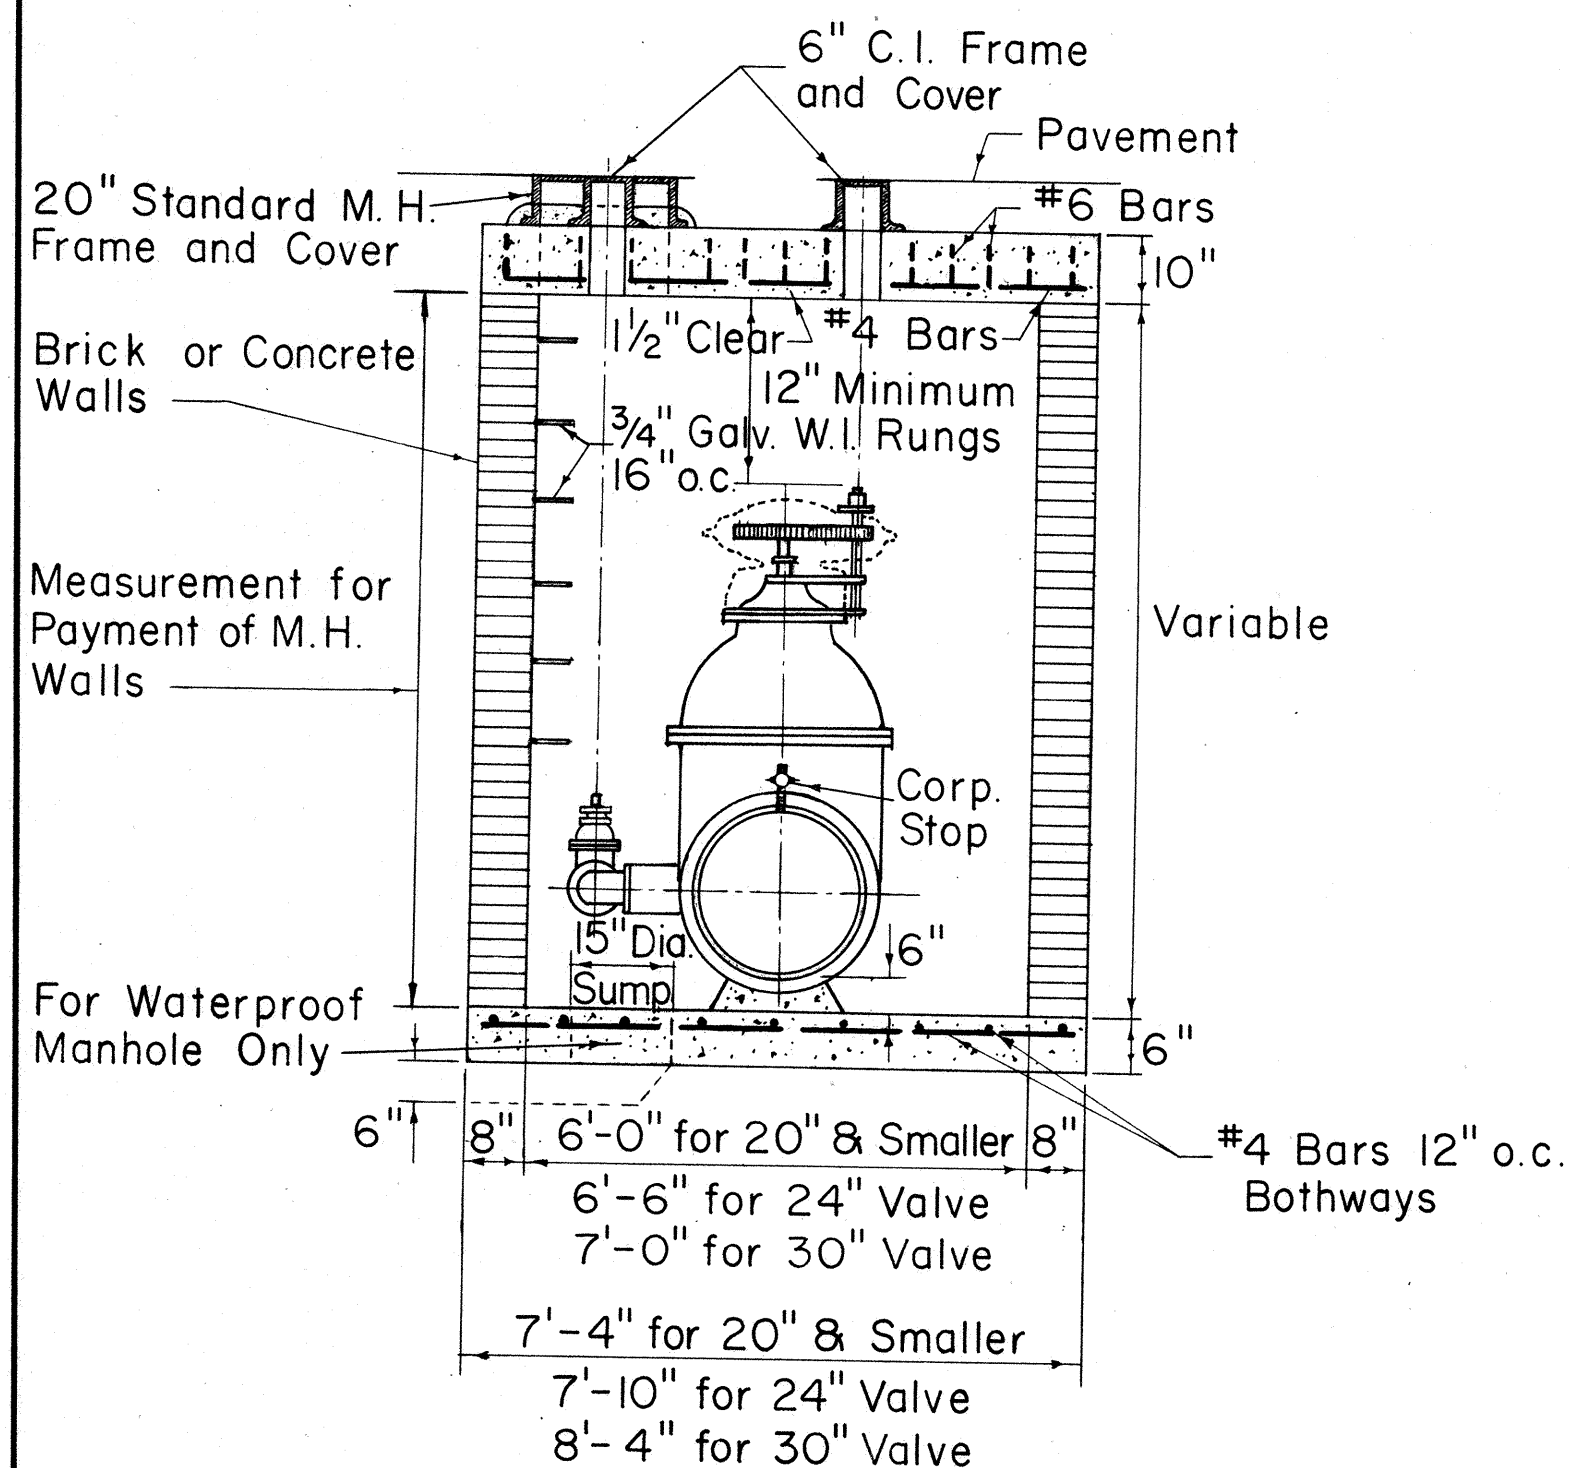


SECTION
TYPE "A" MANHOLE
FOR SPUR GEARED GATE VALVES

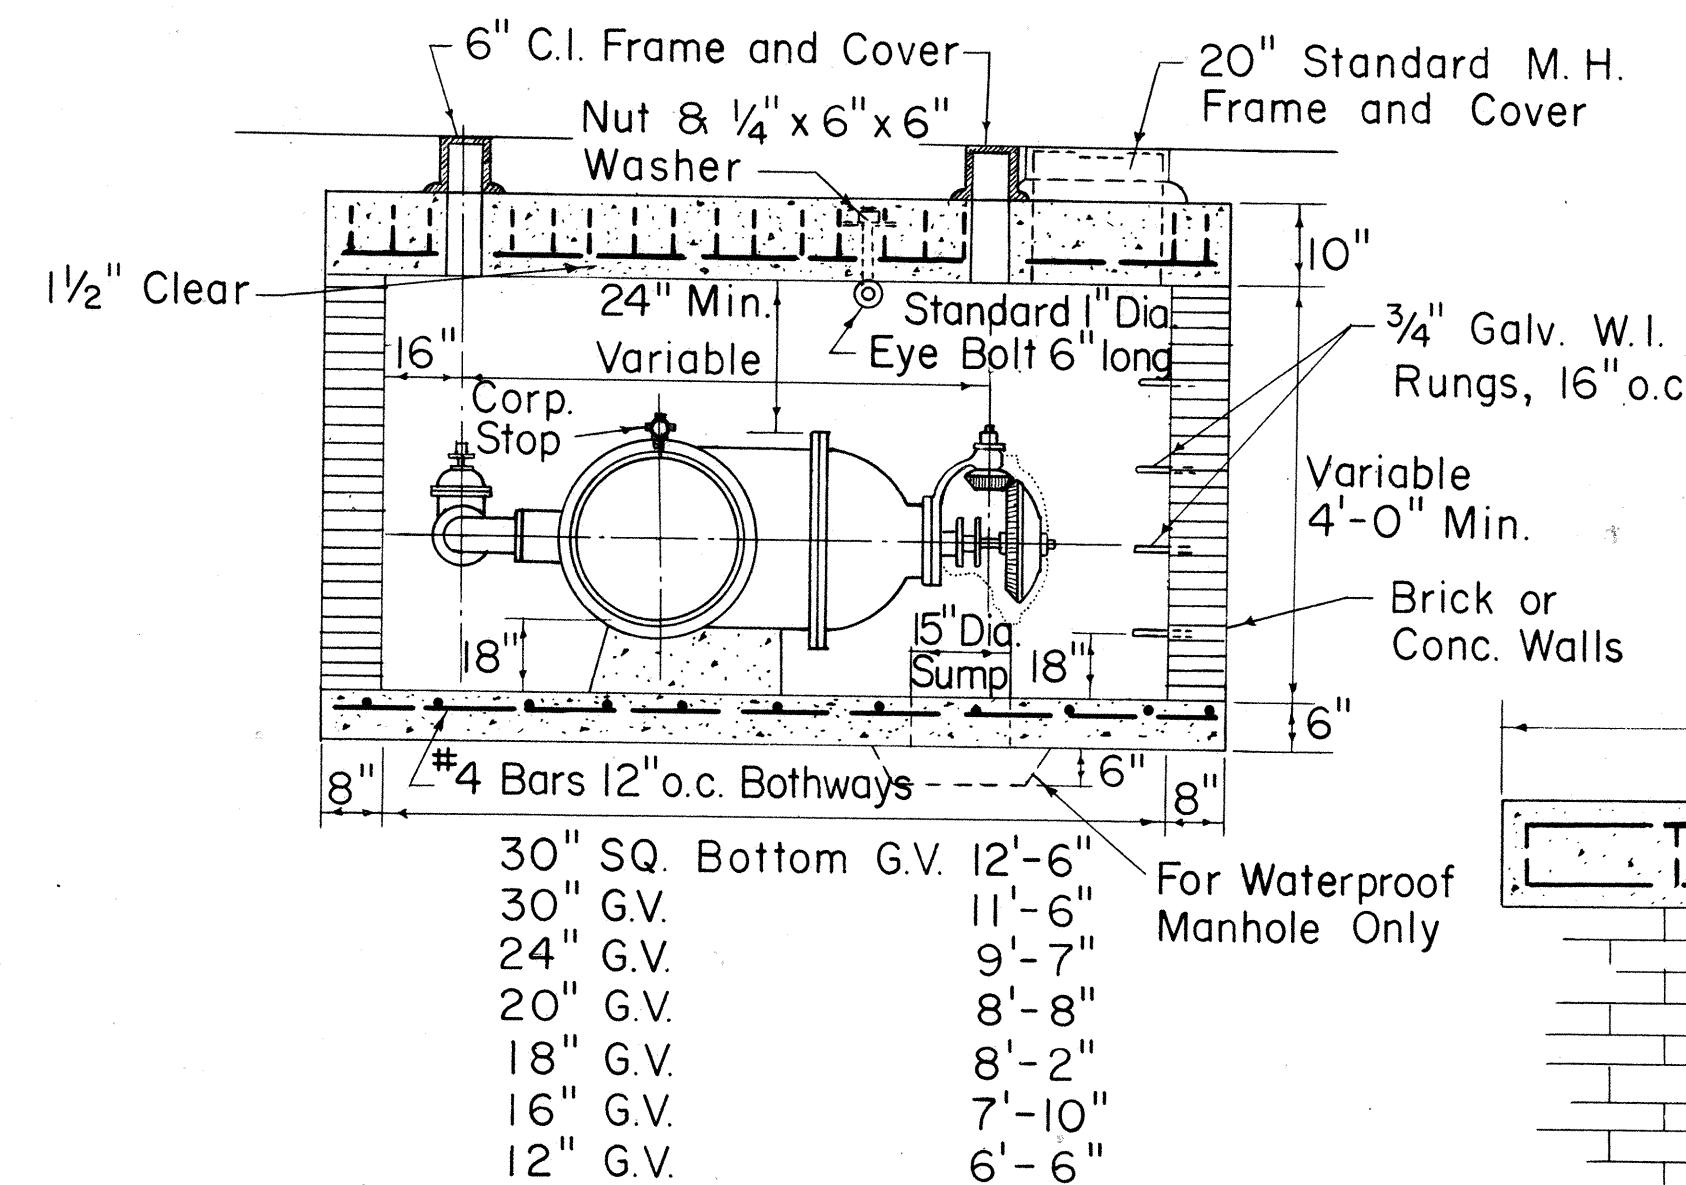


SECTION
TYPE "A" MANHOLE
FOR BEVEL GEARED GATE VALVES


BAR BENDING
DETAIL

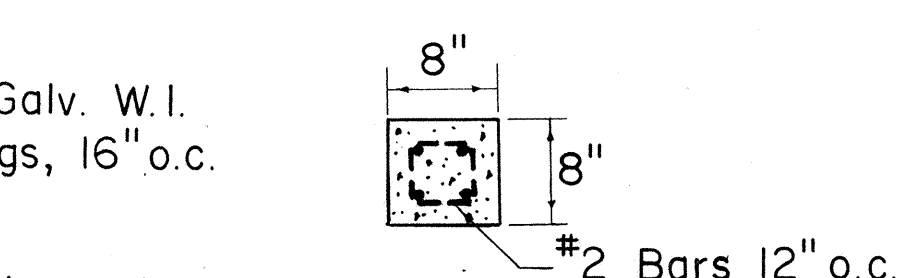


SECTION THRU LINTEL

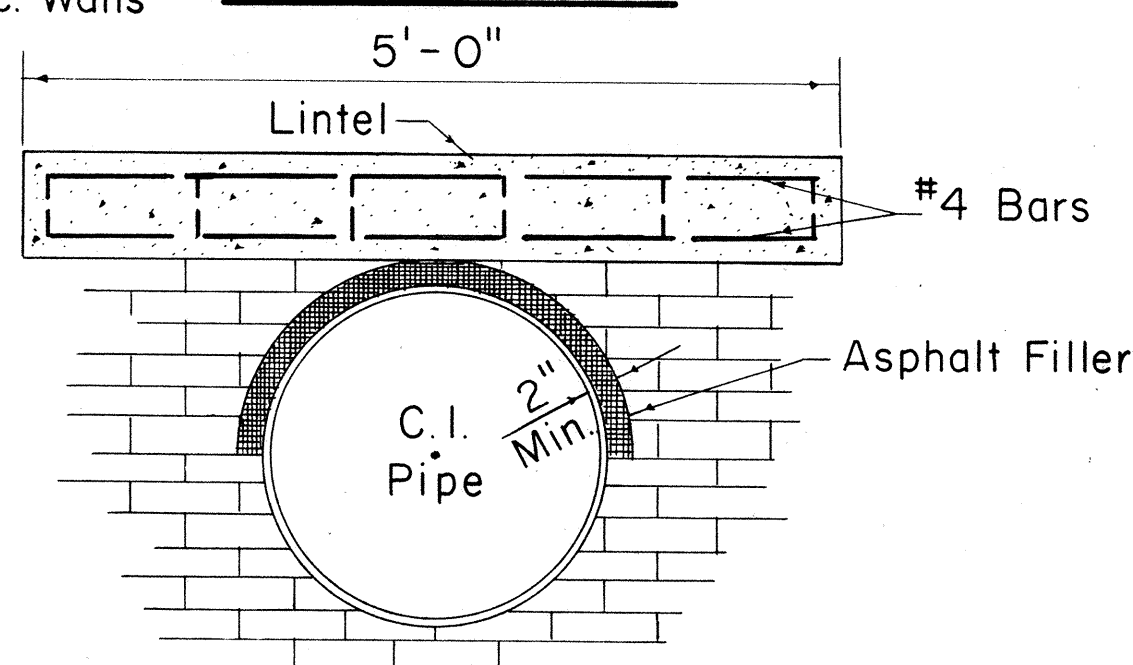

DETAIL OF LINTEL
AND ASPHALT FILLER

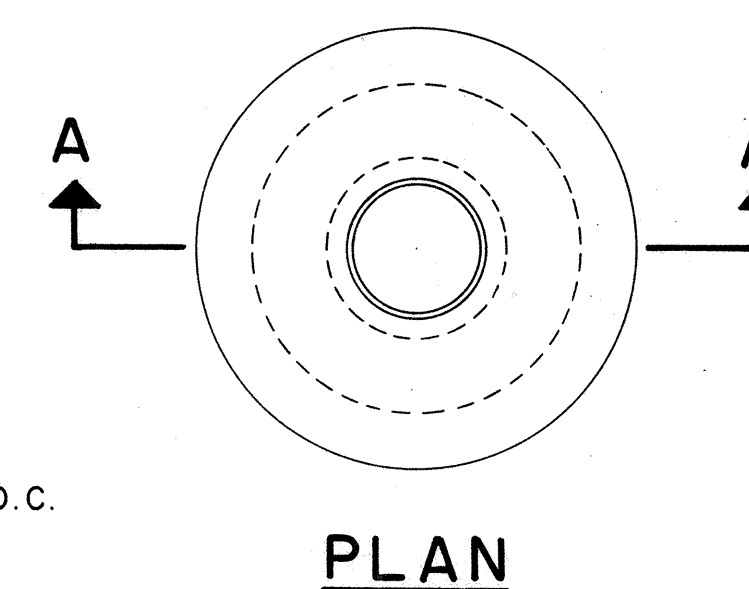

PLAN

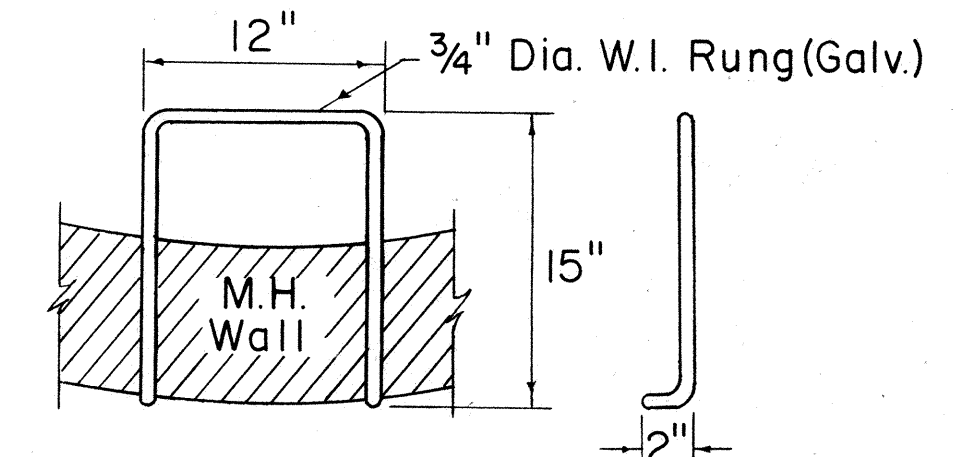

DETAIL OF RUNG

TYPE "B" AND "C" MANHOLES
TYPE "B" 4'-6" DIA. (FOR 12" G.V.)
TYPE "C" 4'-0" DIA. (FOR 6" & 8" G.V.)

APPROVED:

DIRECTOR OF TRANSPORTATION DATE
2-8-66
ASSISTANT CHIEF ENGINEER DATE
BOARD OF WATER SUPPLY


WILSON, OKAMOTO, OKA, INC.
PARK ASSOCIATES, INC.
ARCHITECTS & ENGINEERS

STATE OF HAWAII
DEPARTMENT OF TRANSPORTATION
HIGHWAYS DIVISION
BOARD OF WATER SUPPLY
CITY & COUNTY OF HONOLULU
STANDARD DETAILS
INTERSTATE HIGHWAY (LUNALILO FRWY)
FAI PROJ. NO. I-HI-1(6) UNIT 2
Not to Scale Date: NOVEMBER, 1965
SHEET NO. 10 OF 13 SHEETS


FED. AID DIST. NO.	STATE	FED. AID PROJ. NO.	FISCAL YEAR	SHEET NO.	TOTAL SHEETS
HAWAII	HAWAII	I-H1-1(6) UNIT 2	1966	87	203

NOTE:


Reinforced concrete manhole walls (See detail of plain manhole) shall be used for portions below the water table.

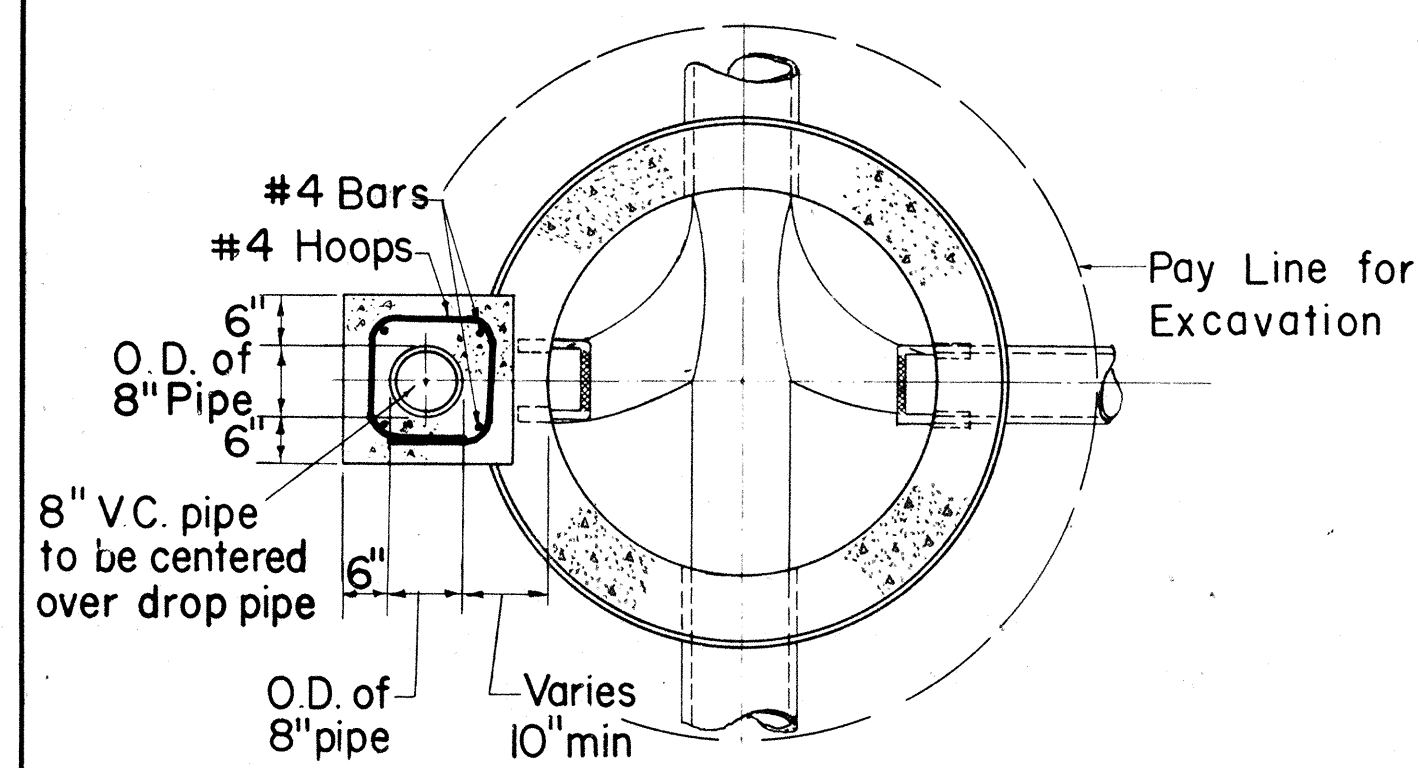


SECTION A-A
Scale: 1/2" = 1'-0"

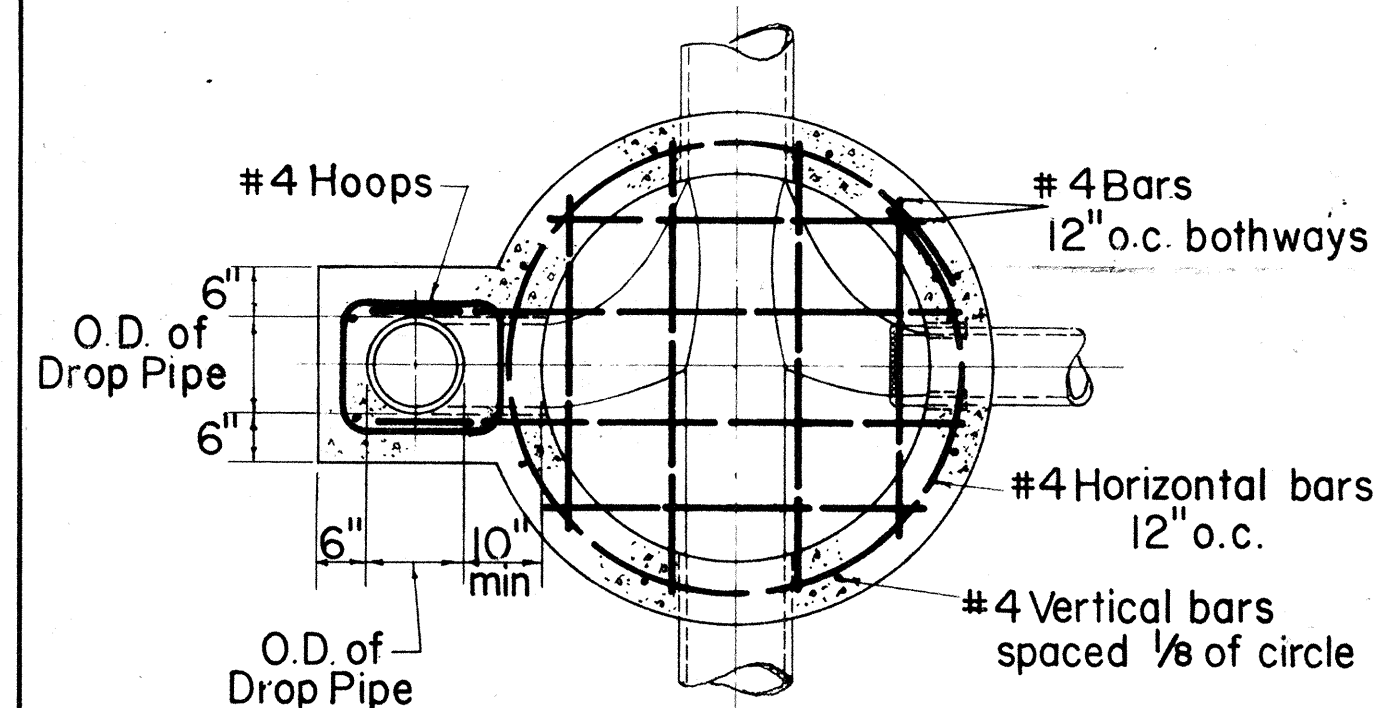


SECTION B-B
Scale: 1/2" = 1'-0"

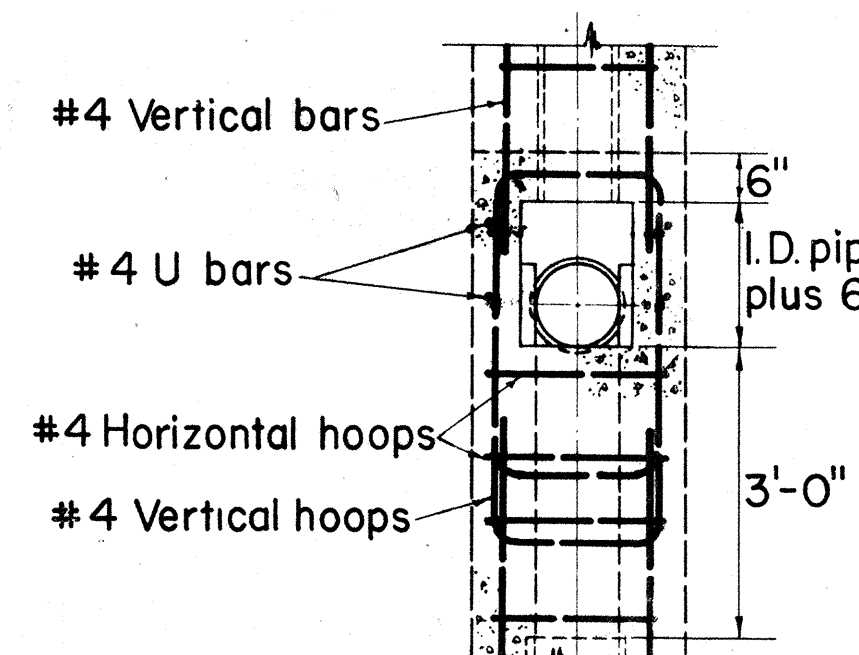


SECTION C-C
Scale: 1/2" = 1'-0"

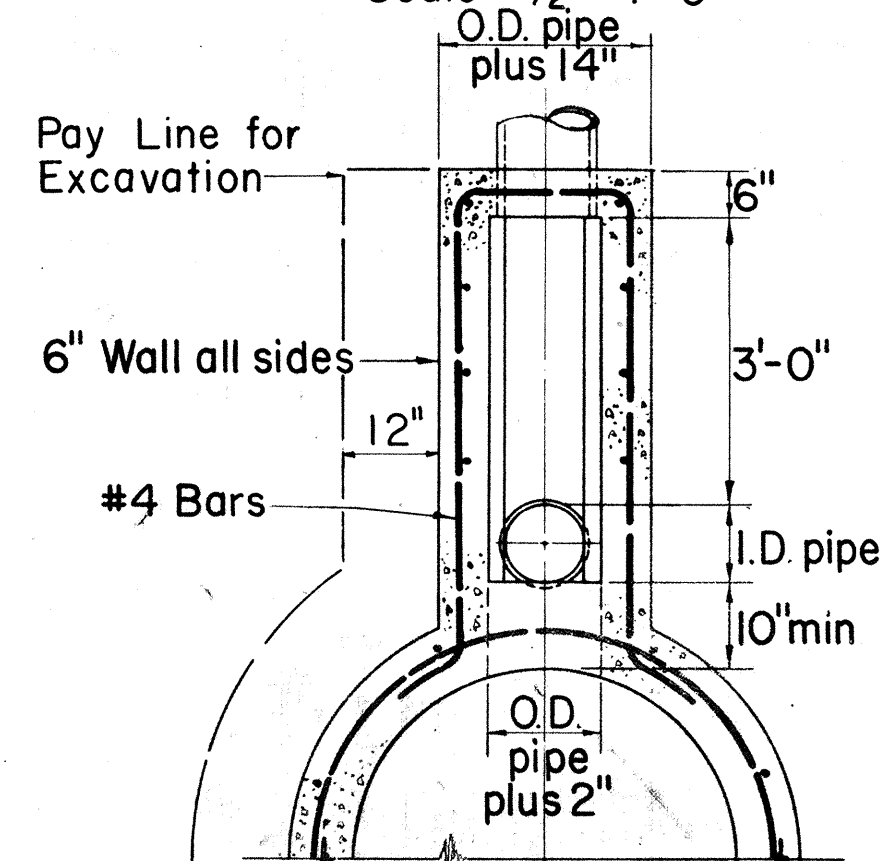


SECTION D-D
Scale: 1/2" = 1'-0"

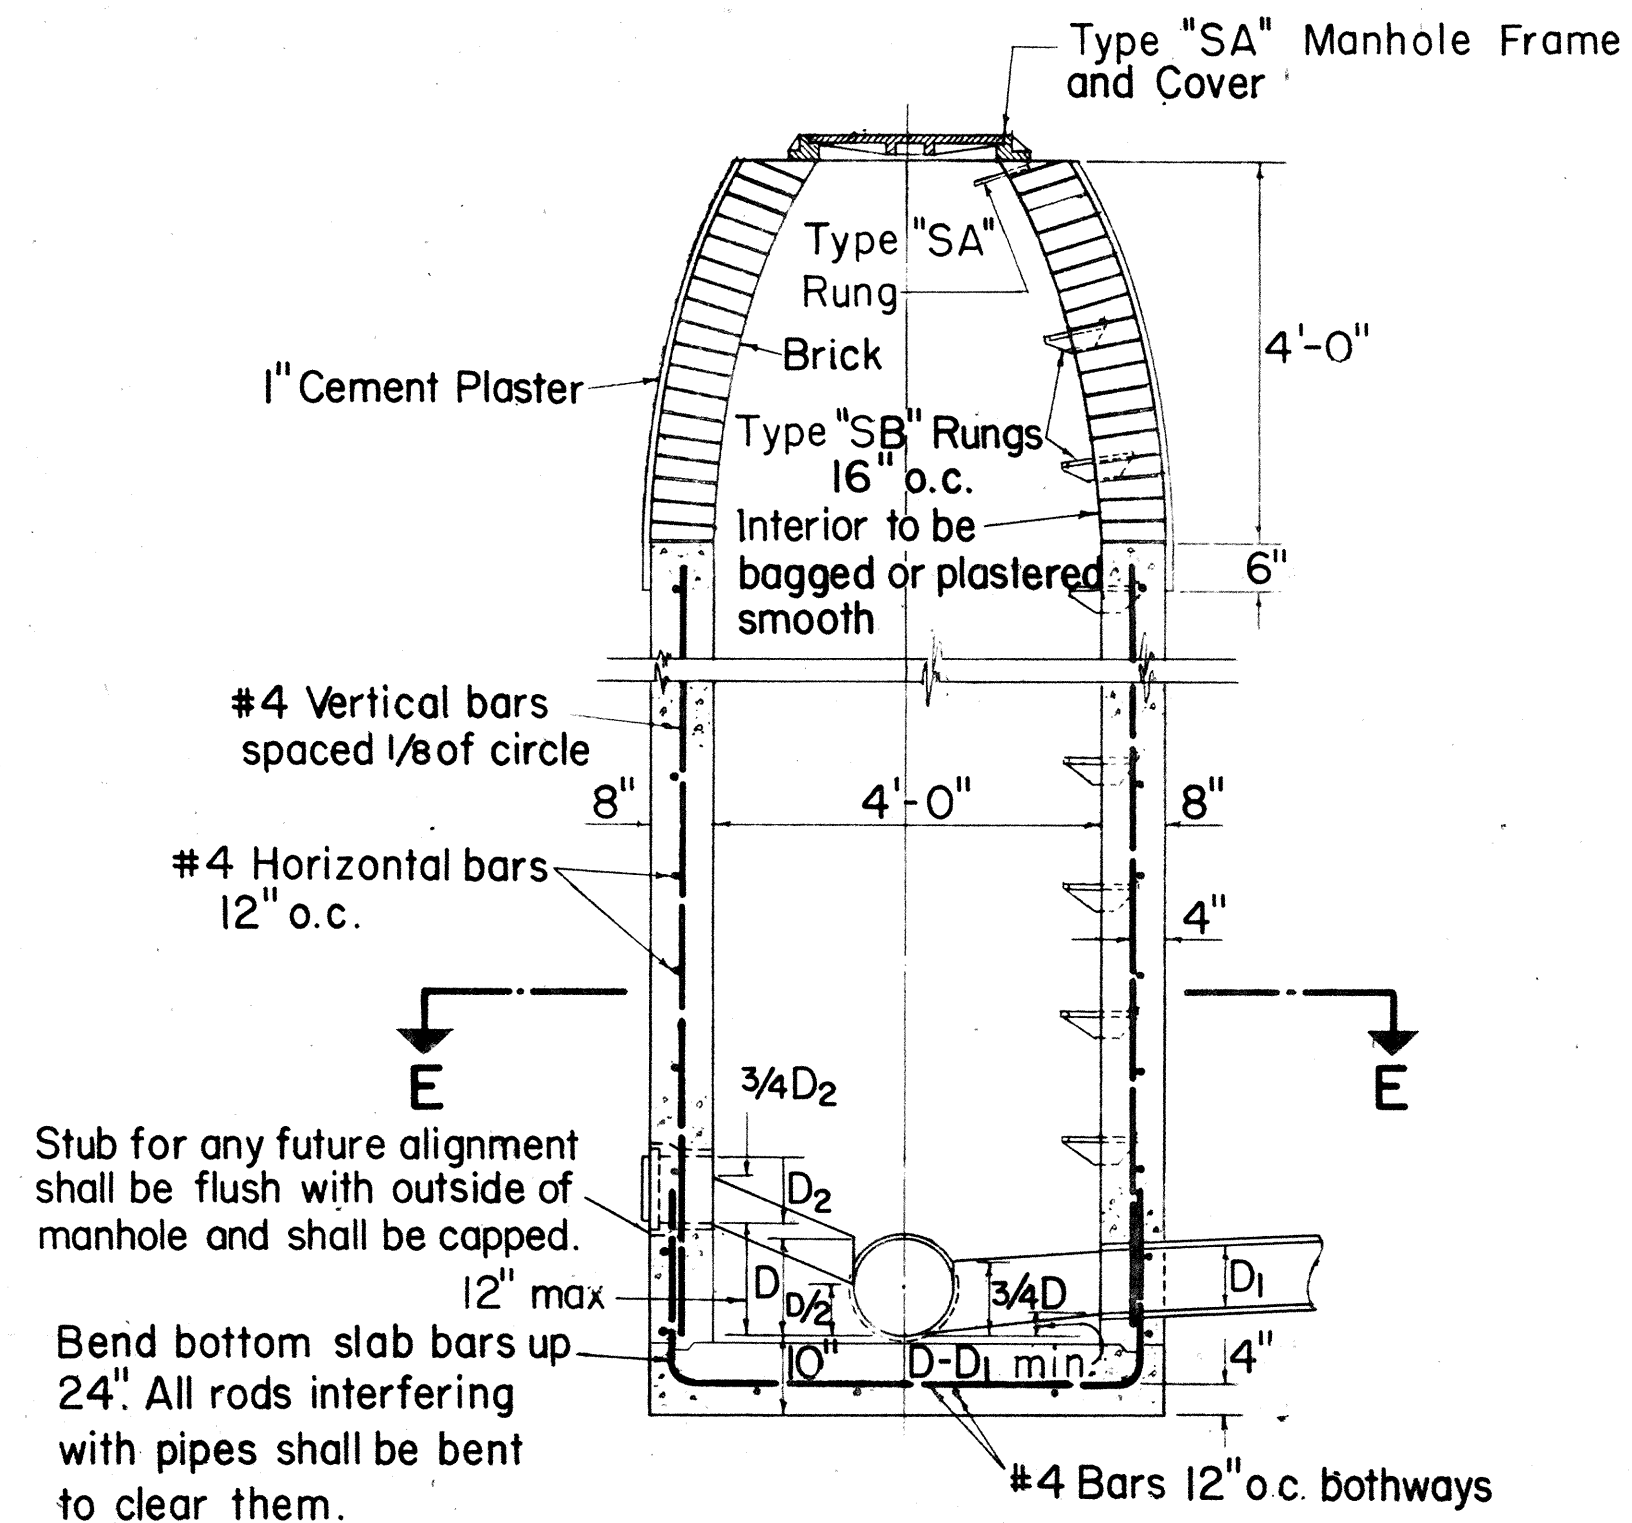


PLAIN MANHOLE
Scale: 1/2" = 1'-0"

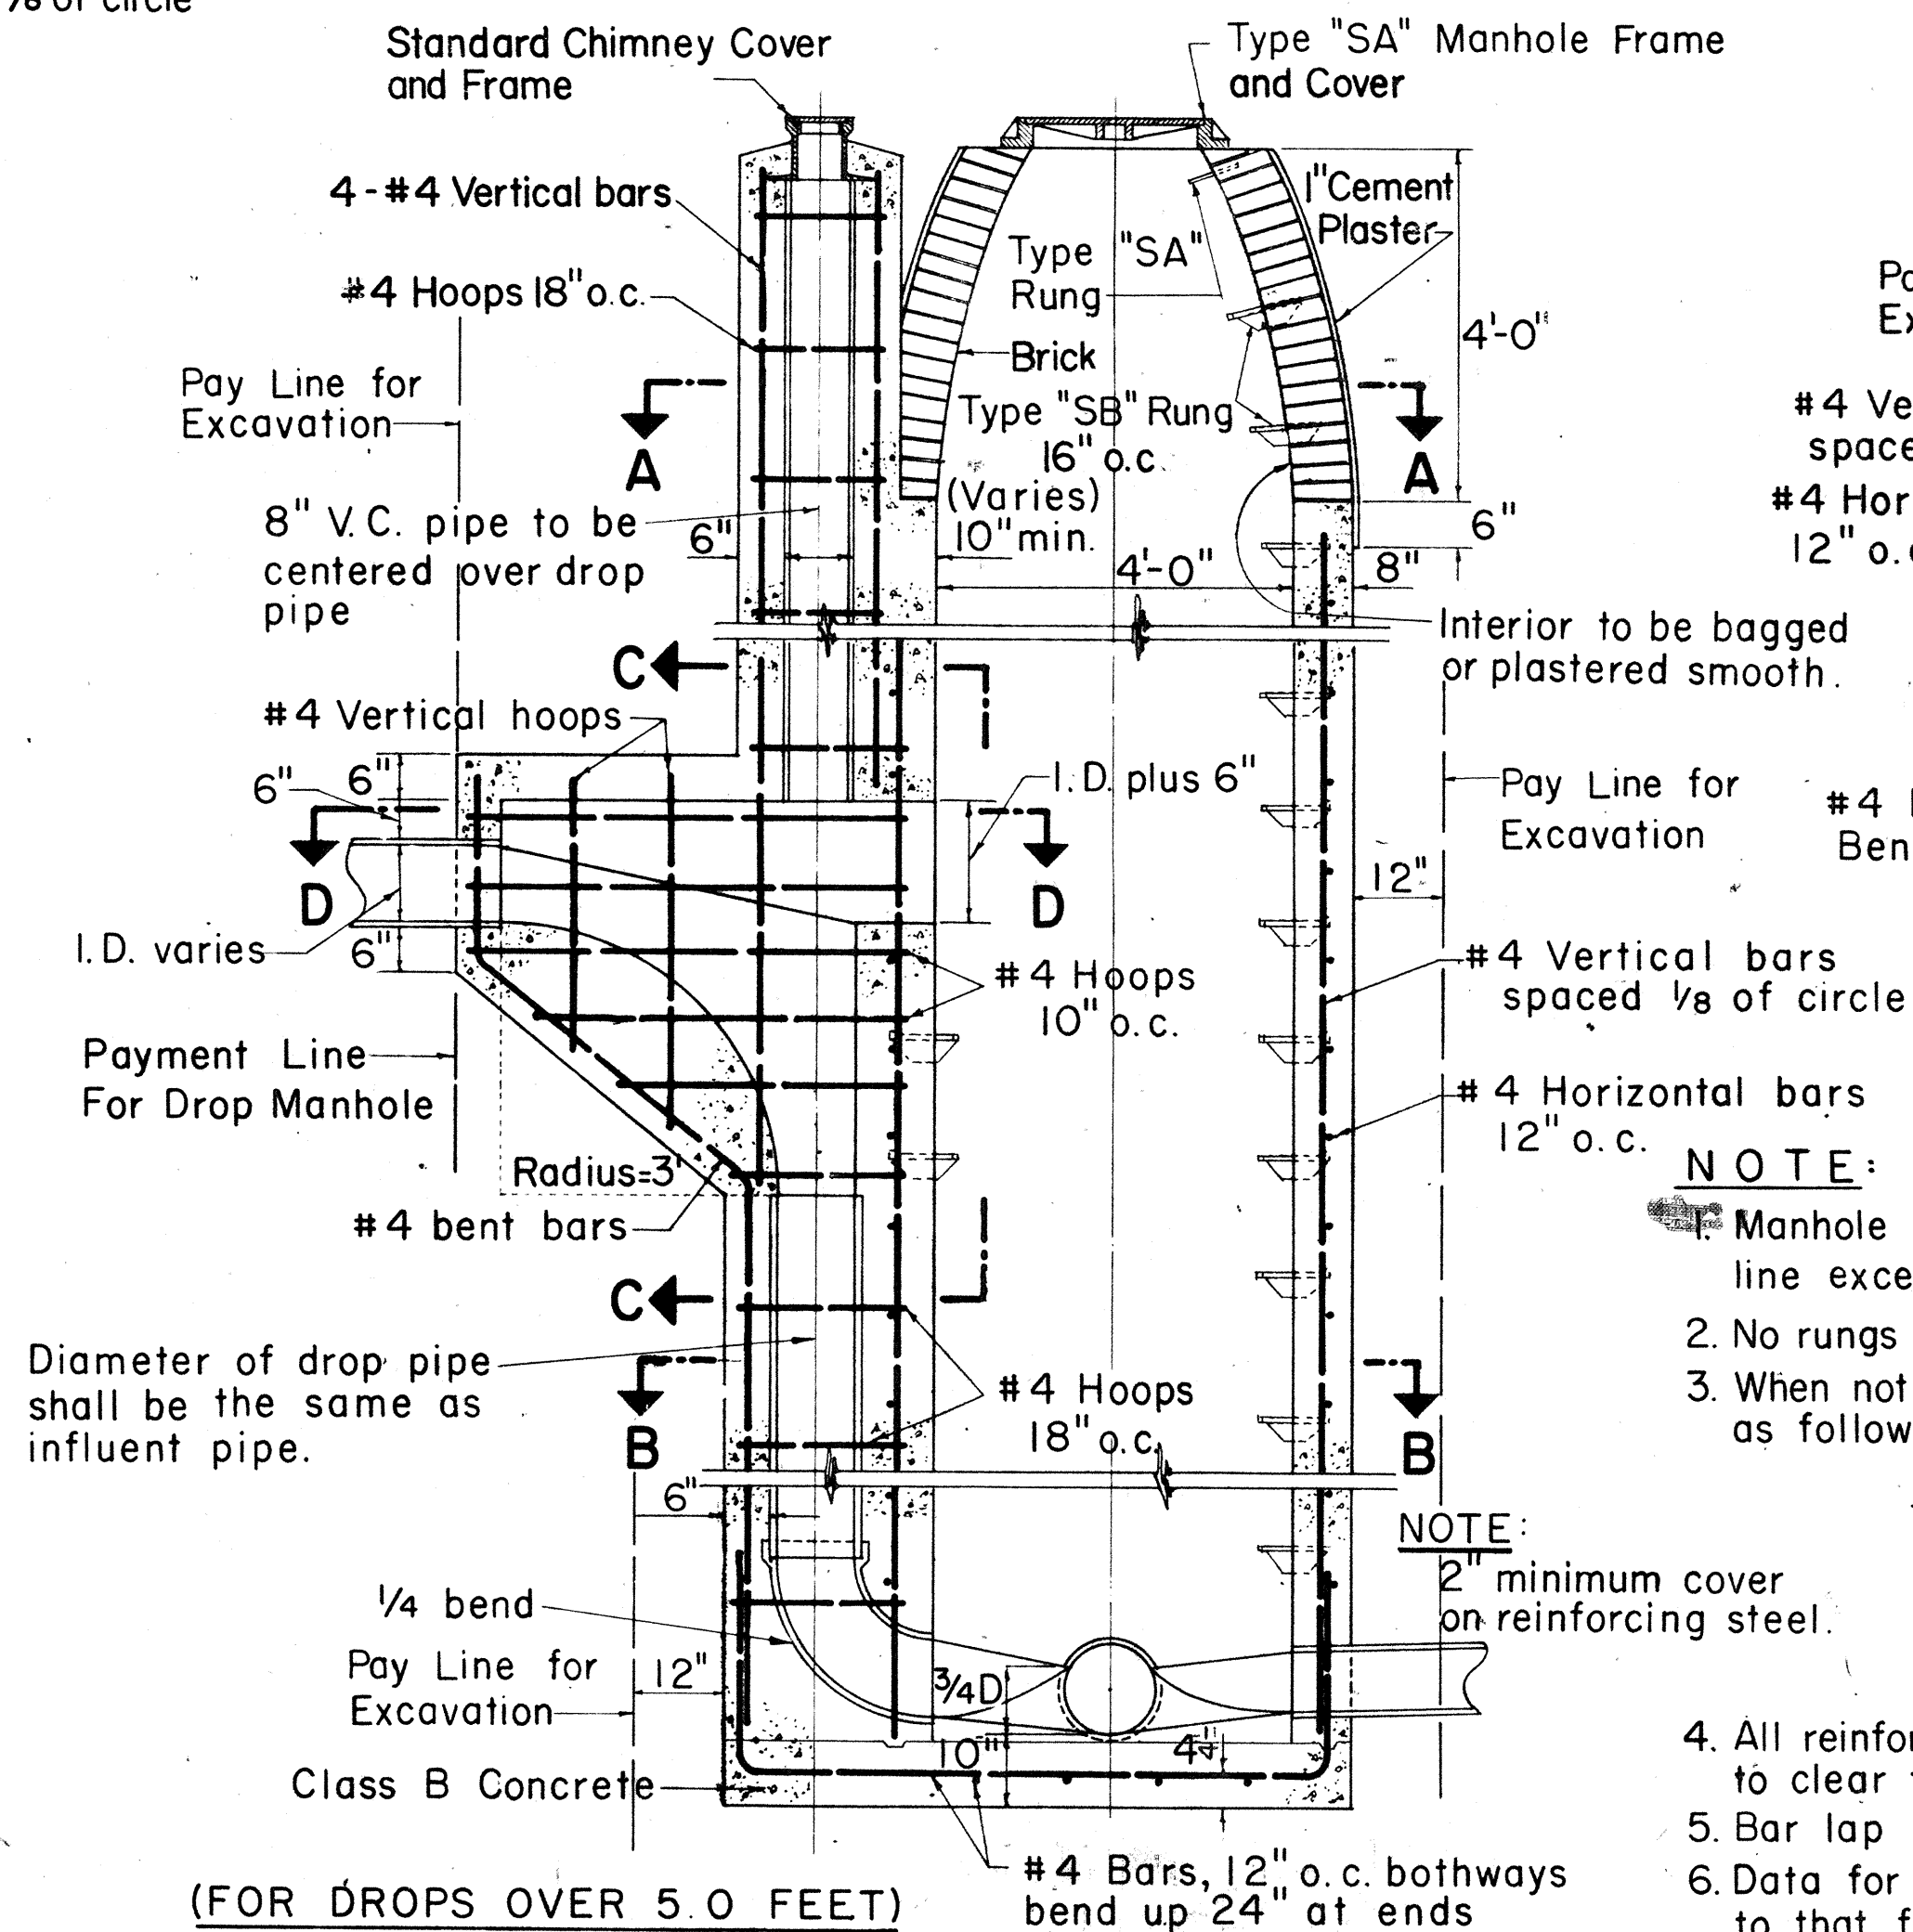

DROP MANHOLE
Scale: 1/2" = 1'-0"

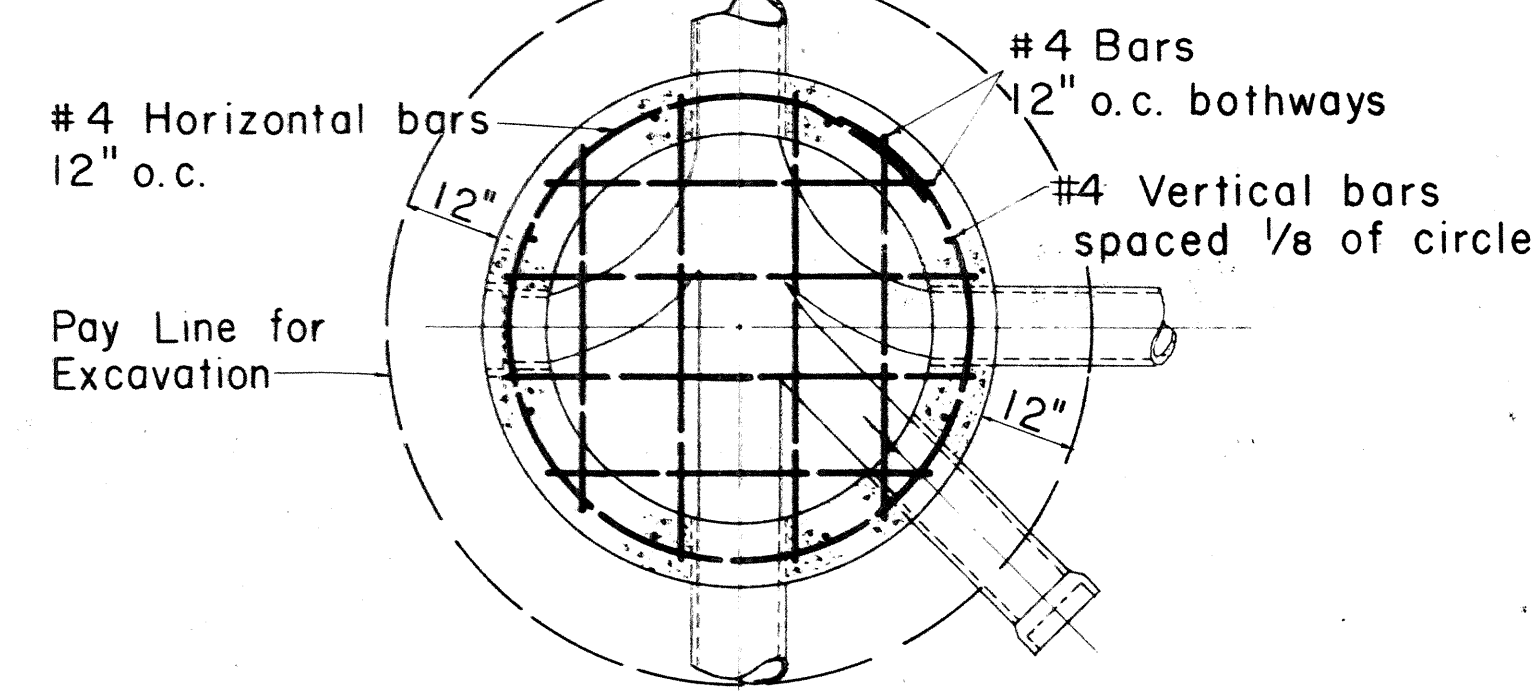

SECTION E-E
Scale: 1/2" = 1'-0"

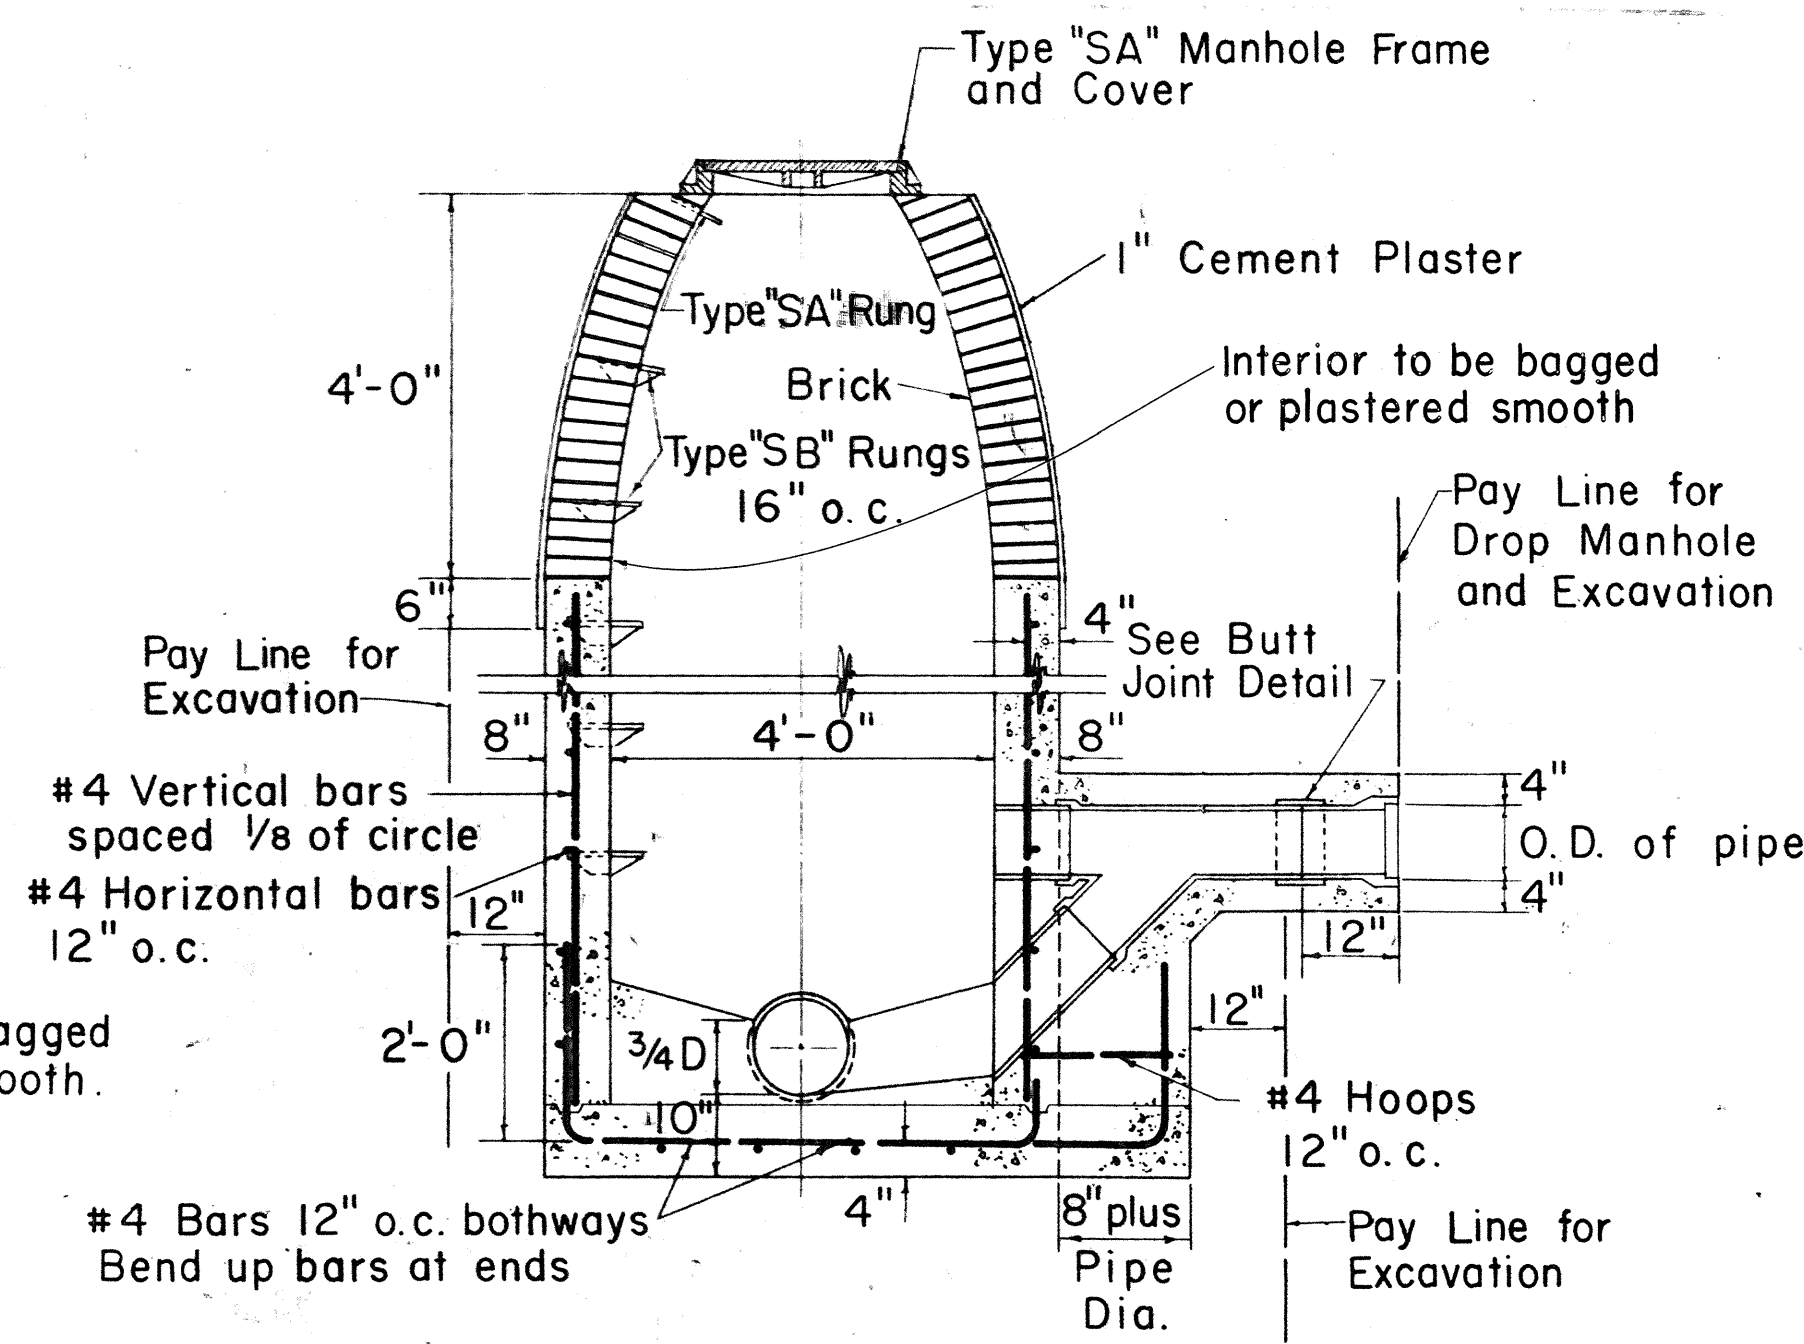

SHALLOW DROP MANHOLE
Scale: 1/2" = 1'-0"

NOTE:

- Manhole rungs shall not be aligned above any flow line except in drop manhole.
- No rungs shall be installed in manholes less than 3 feet high.
- When not otherwise noted, manhole stubs shall be sloped as follows:

Pipe Size	Rise Per Foot
6"	1/8"
8"	3/32"
10"	1/16"
12"	1/16"


- All reinforcing rods interfering with pipes shall be bent to clear them.
- Bar lap to be 40 diameters in length.
- Data for special manholes not shown shall be similar to that for plain manholes.
- Size of drop pipe in all Drop Manholes shall be same as influent line.

- Manhole wall to be of reinforced concrete to height 1' above normal ground water table.

APPROVED:

SEWER SYSTEM DIRECTOR,
DIVISION OF SEWERS

DATE

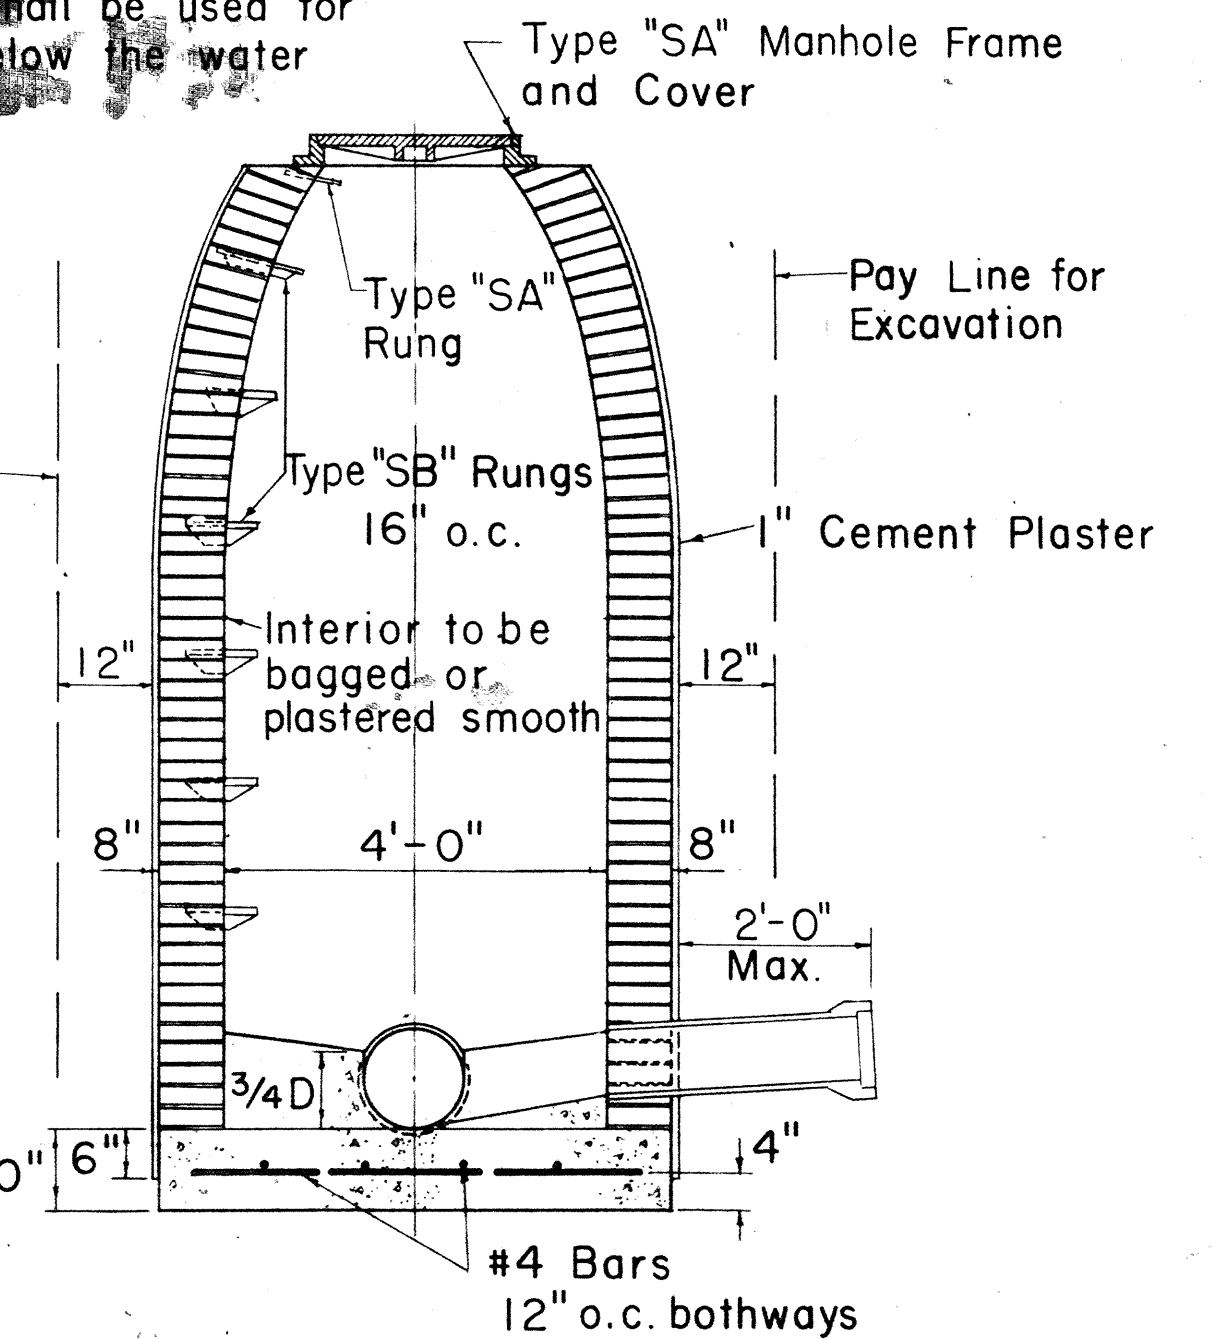

BRICK MANHOLE
Scale: 1/2" = 1'-0"


Payment for excavation for manholes shall be made under unit price for trench excavation and shall be measured to one foot outside of walls from original ground elevation to authorized bottom elevation.
Payment for manhole walls (brick, or cast-in-place concrete) shall include brick, mortar, concrete, reinforcing steel, cast-iron steps, galvanized wrought iron rungs, and plastering.

STATE OF HAWAII
DEPARTMENT OF TRANSPORTATION
HIGHWAYS DIVISION
DIVISION OF SEWERS
CITY & COUNTY OF HONOLULU


STANDARD DETAILS
SEWERS - DROP MANHOLE AND
BRICK MANHOLE DETAILS
INTERSTATE HIGHWAY (LUNALILO FREEWAY)
F.A.I. PROJ. No. I-H1-1(6) UNIT 2
Scale: As Noted Date: NOVEMBER 1965

SHEET NO. 11 OF 13 SHEETS


FED AID DIST. NO.	STATE	FED AID PROJ. NO.	FISCAL YEAR	SHEET NO.	TOTAL SHEETS
HAWAII	HAWAII	I-HI-1(6) UNIT 2	1966	89	203

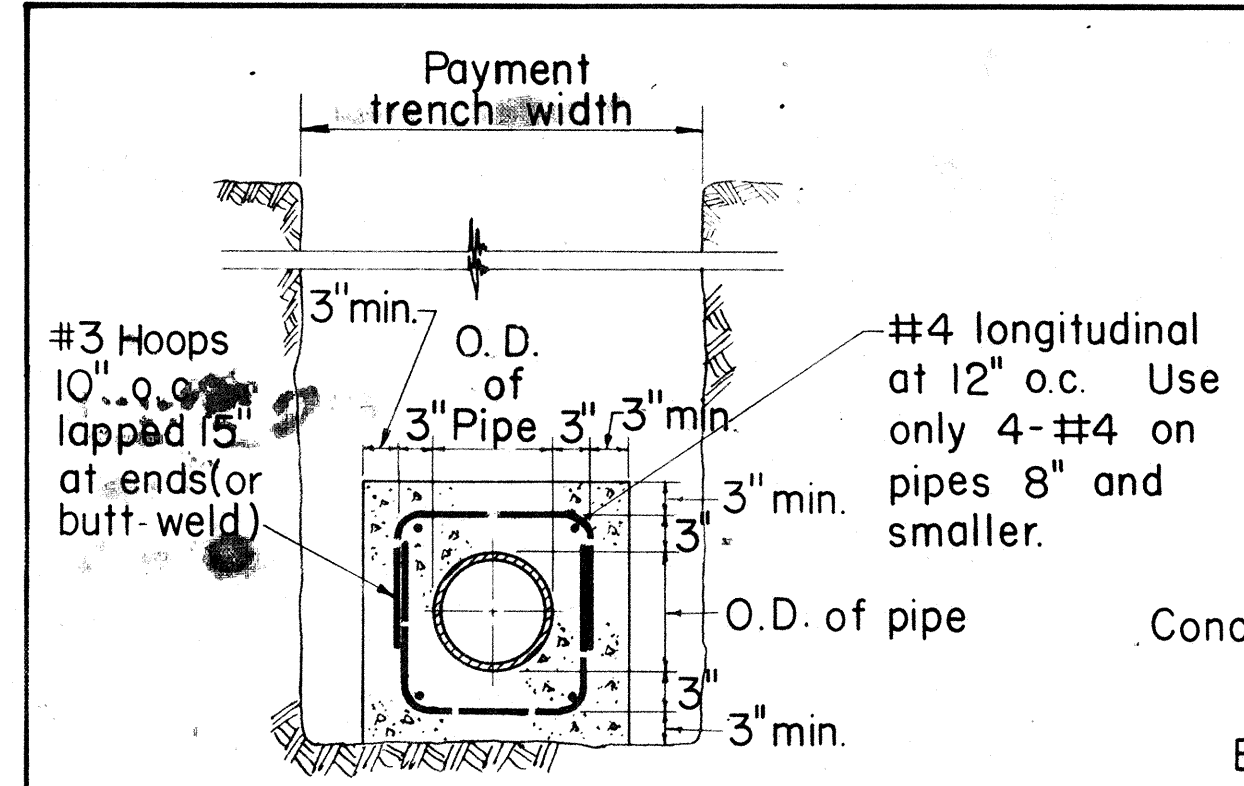


DETAIL OF CONCRETE JACKET
Scale: 3/4" = 1'-0"

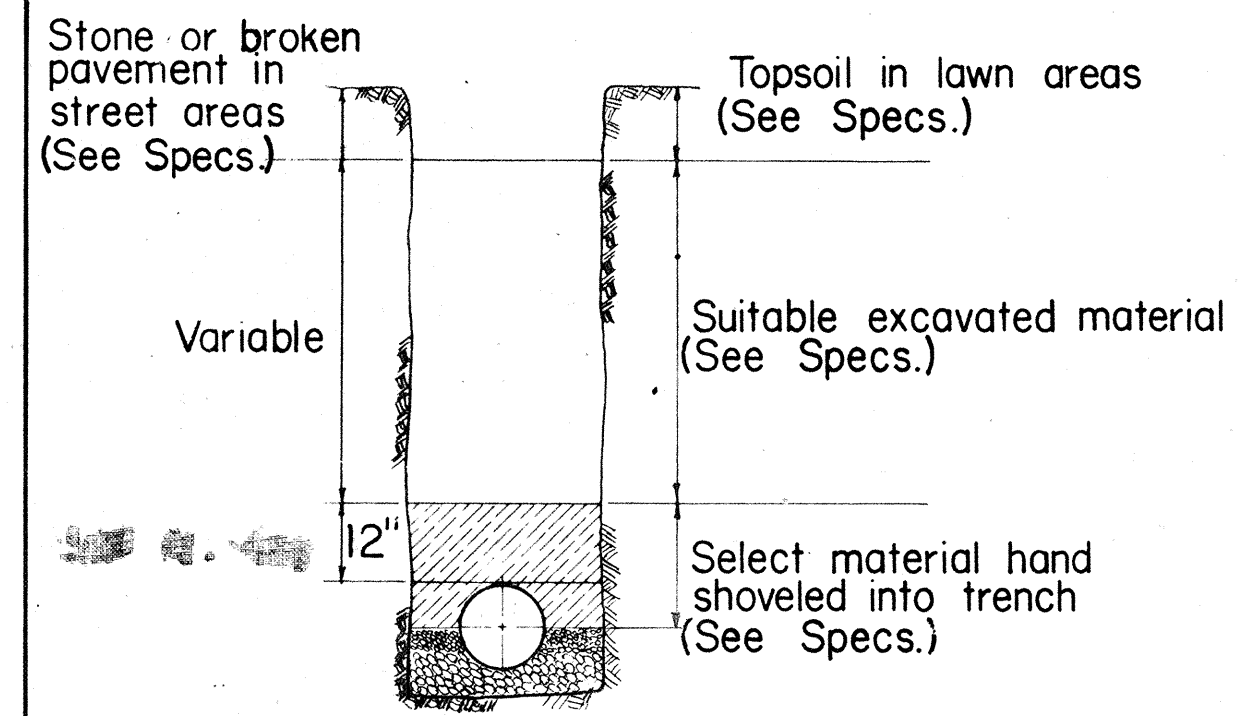

METHOD OF BACKFILL
Not To Scale

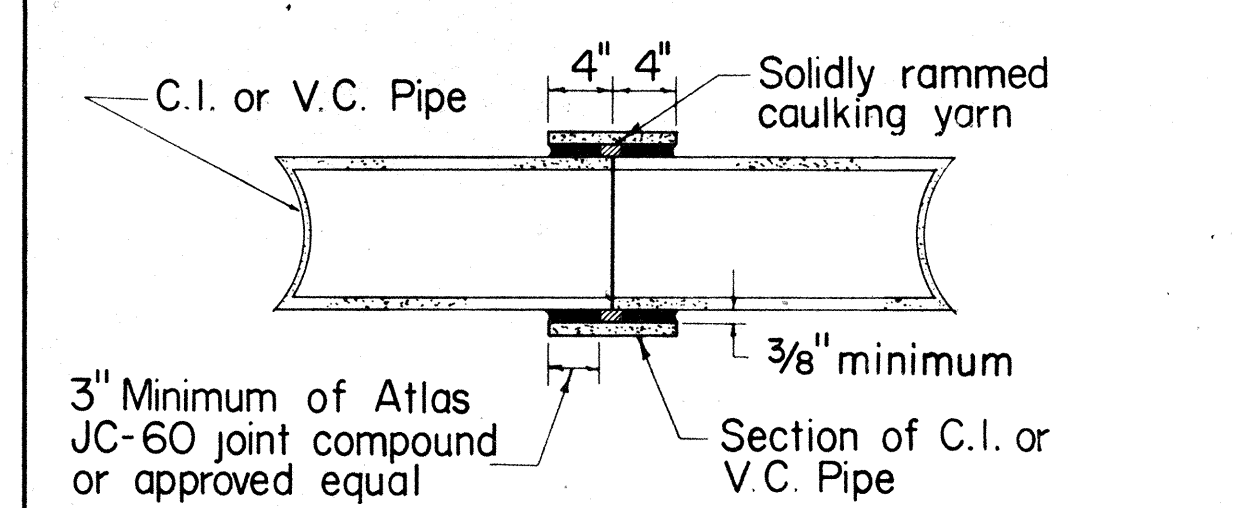


BUTT JOINT DETAIL
Scale: 1" = 1'-0"

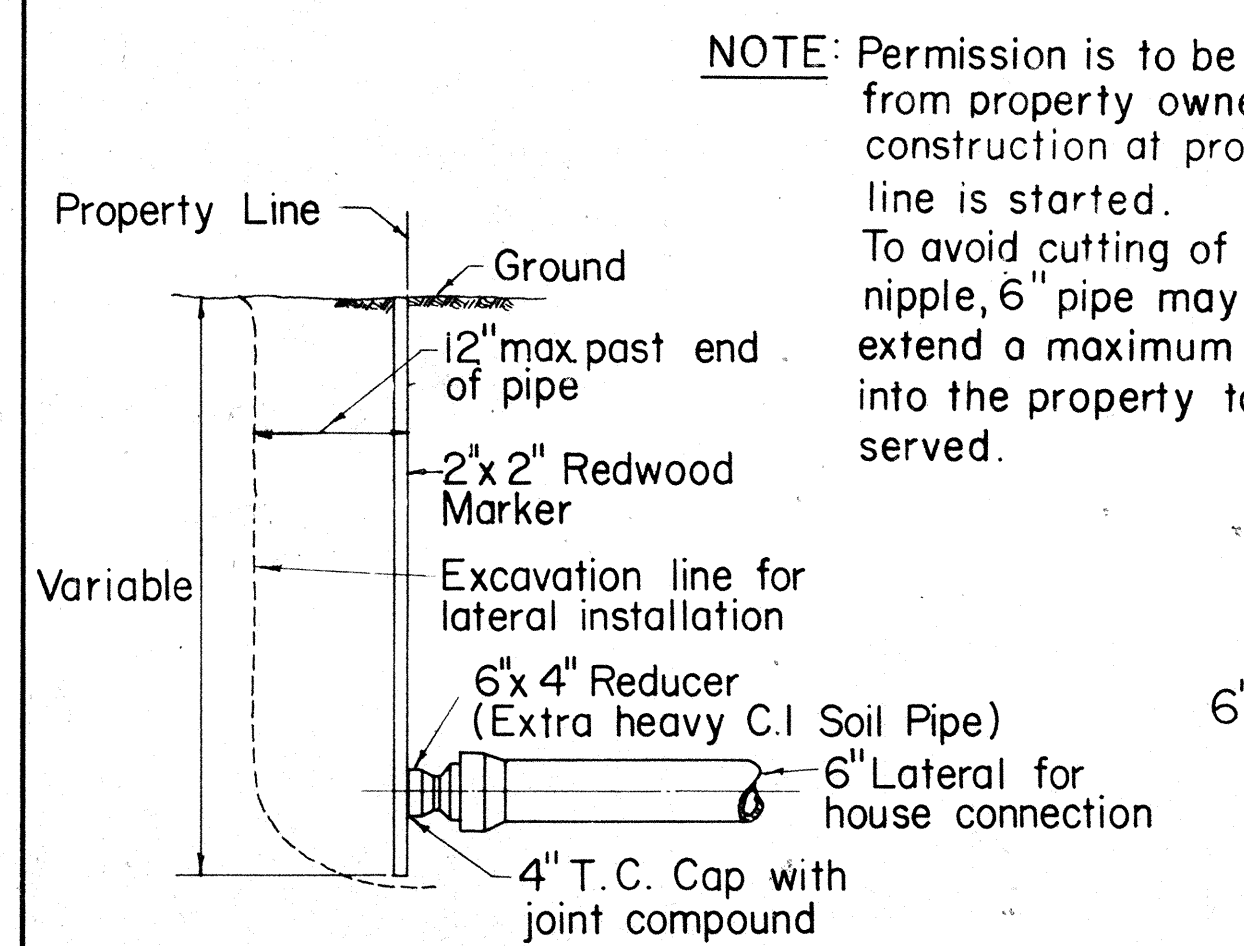


DETAIL AT PROPERTY LINE

CONSTRUCTION OF LATERALS
Not To Scale

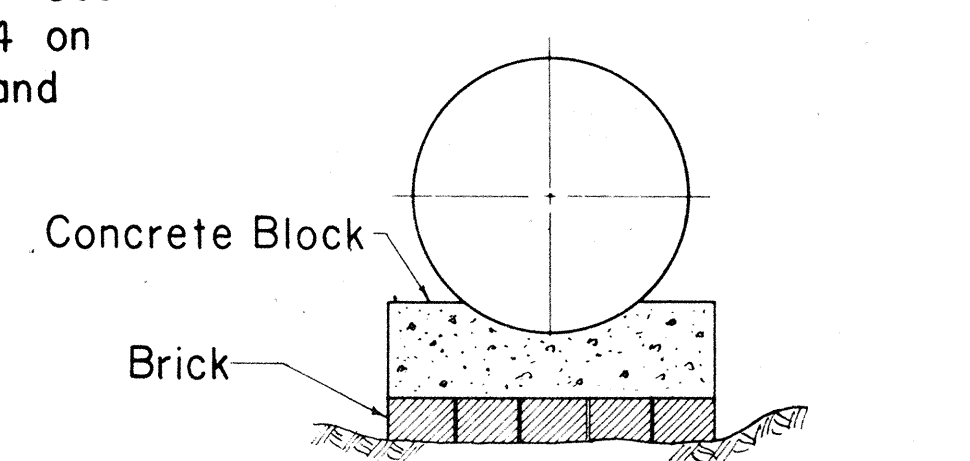


METHOD OF USING BRICKS UNDER CONCRETE BLOCKS
Not To Scale

Contractor shall set Concrete Blocks on undisturbed ground. Where ground is too low, the contractor shall not heap up dirt under the Concrete Block but use Concrete Bricks to take up the deficiency, scraping away beneath Concrete Block to give sufficient room for Brick.

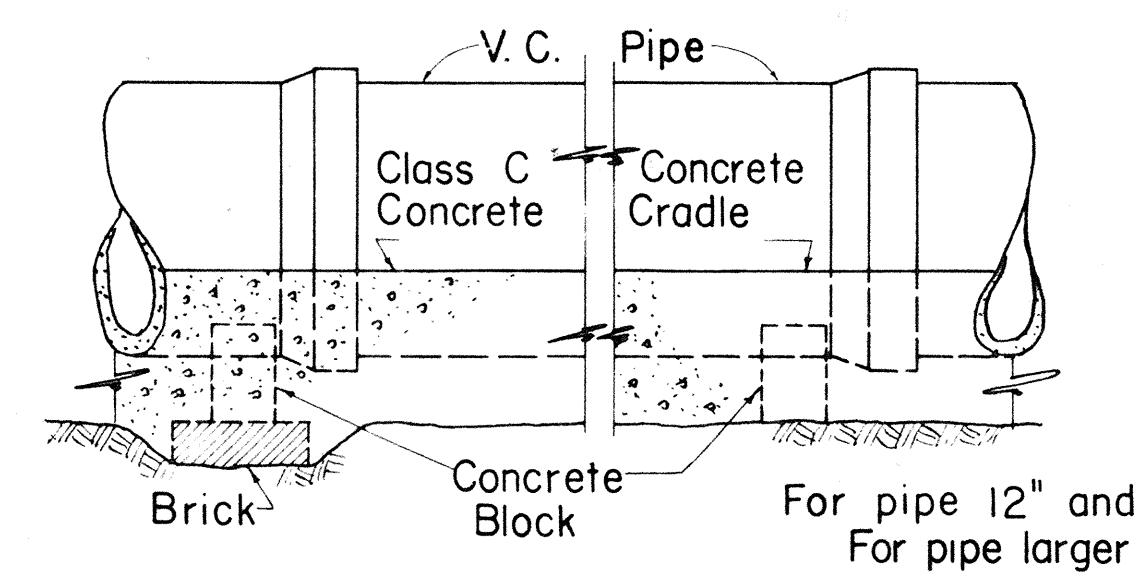


ELEVATION SHOWING METHOD OF LAYING PIPE
Not To Scale

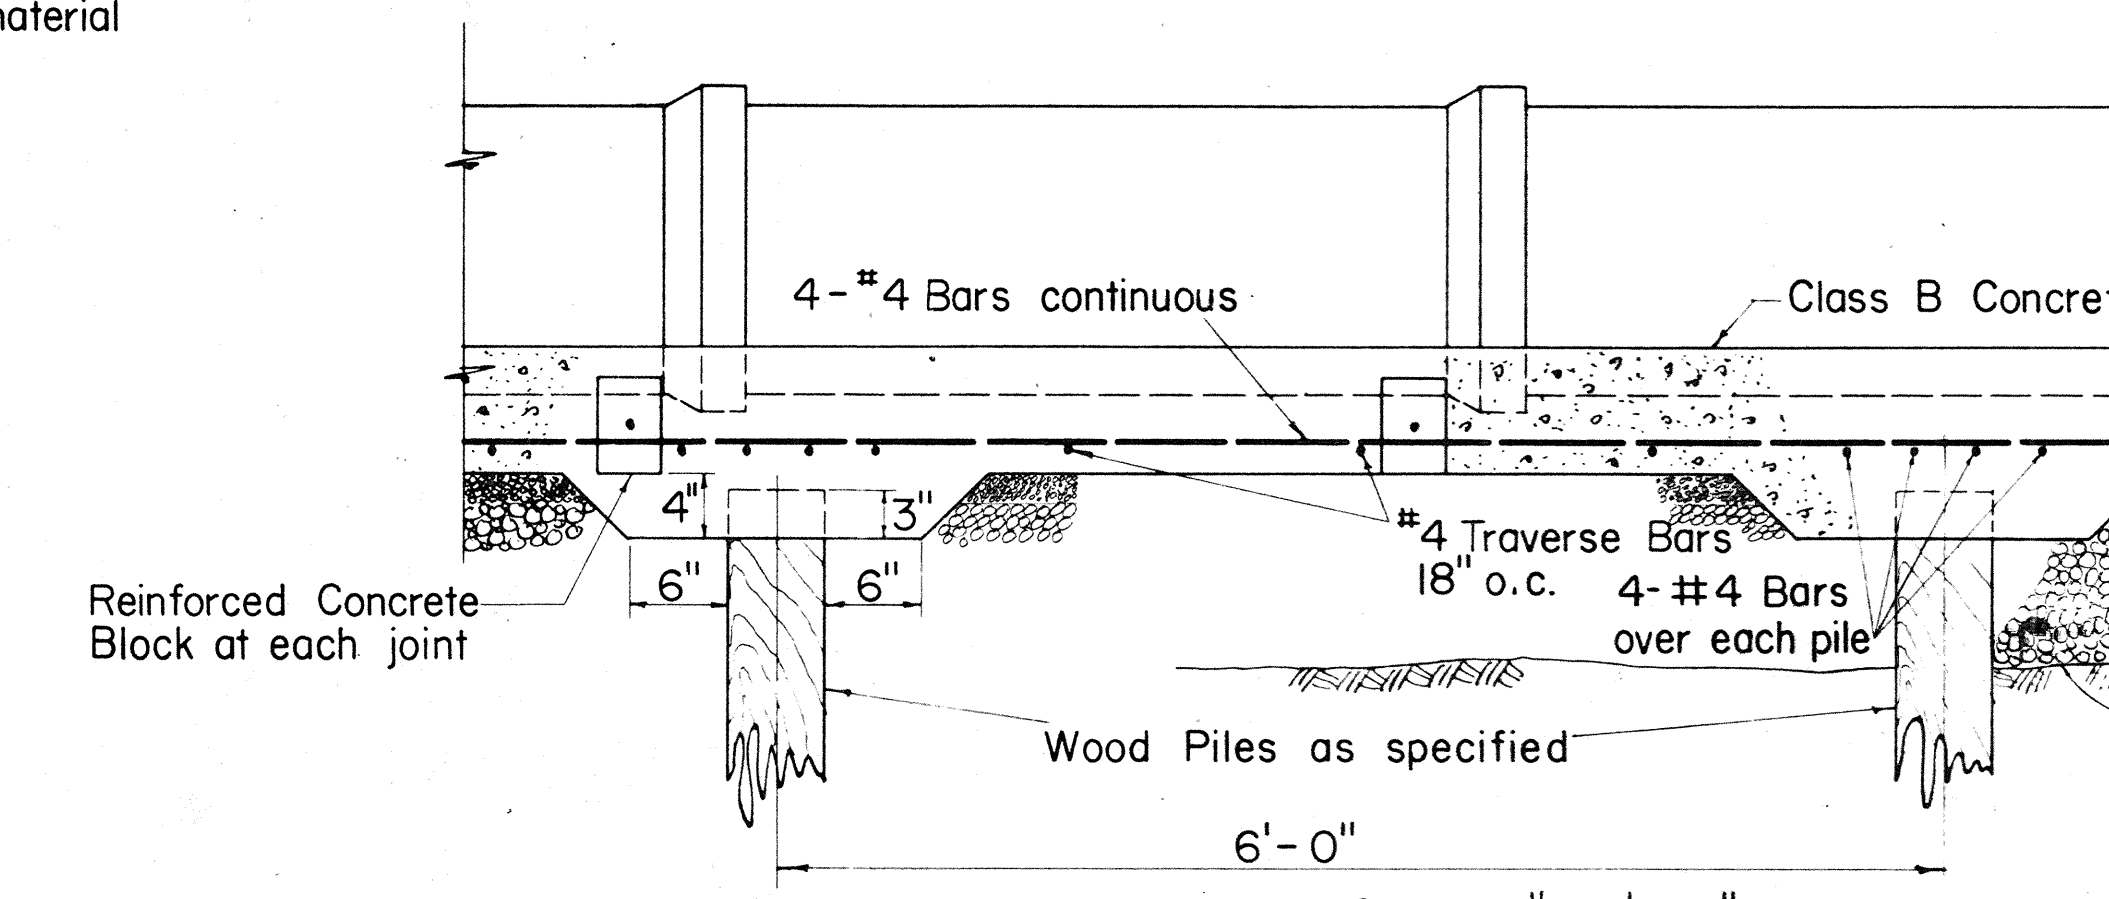

DETAIL OF REINFORCED CONCRETE CRADLE ON WOOD PILES
(FOR 6, 8, 10 & 12 IN. V.C. PIPE)
Scale: 1" = 1'-0"


DETAIL OF REINFORCED CONCRETE CRADLE WITHOUT PILES
SIMILAR EXCEPT FOR WOOD PILES AND PILE CAPS

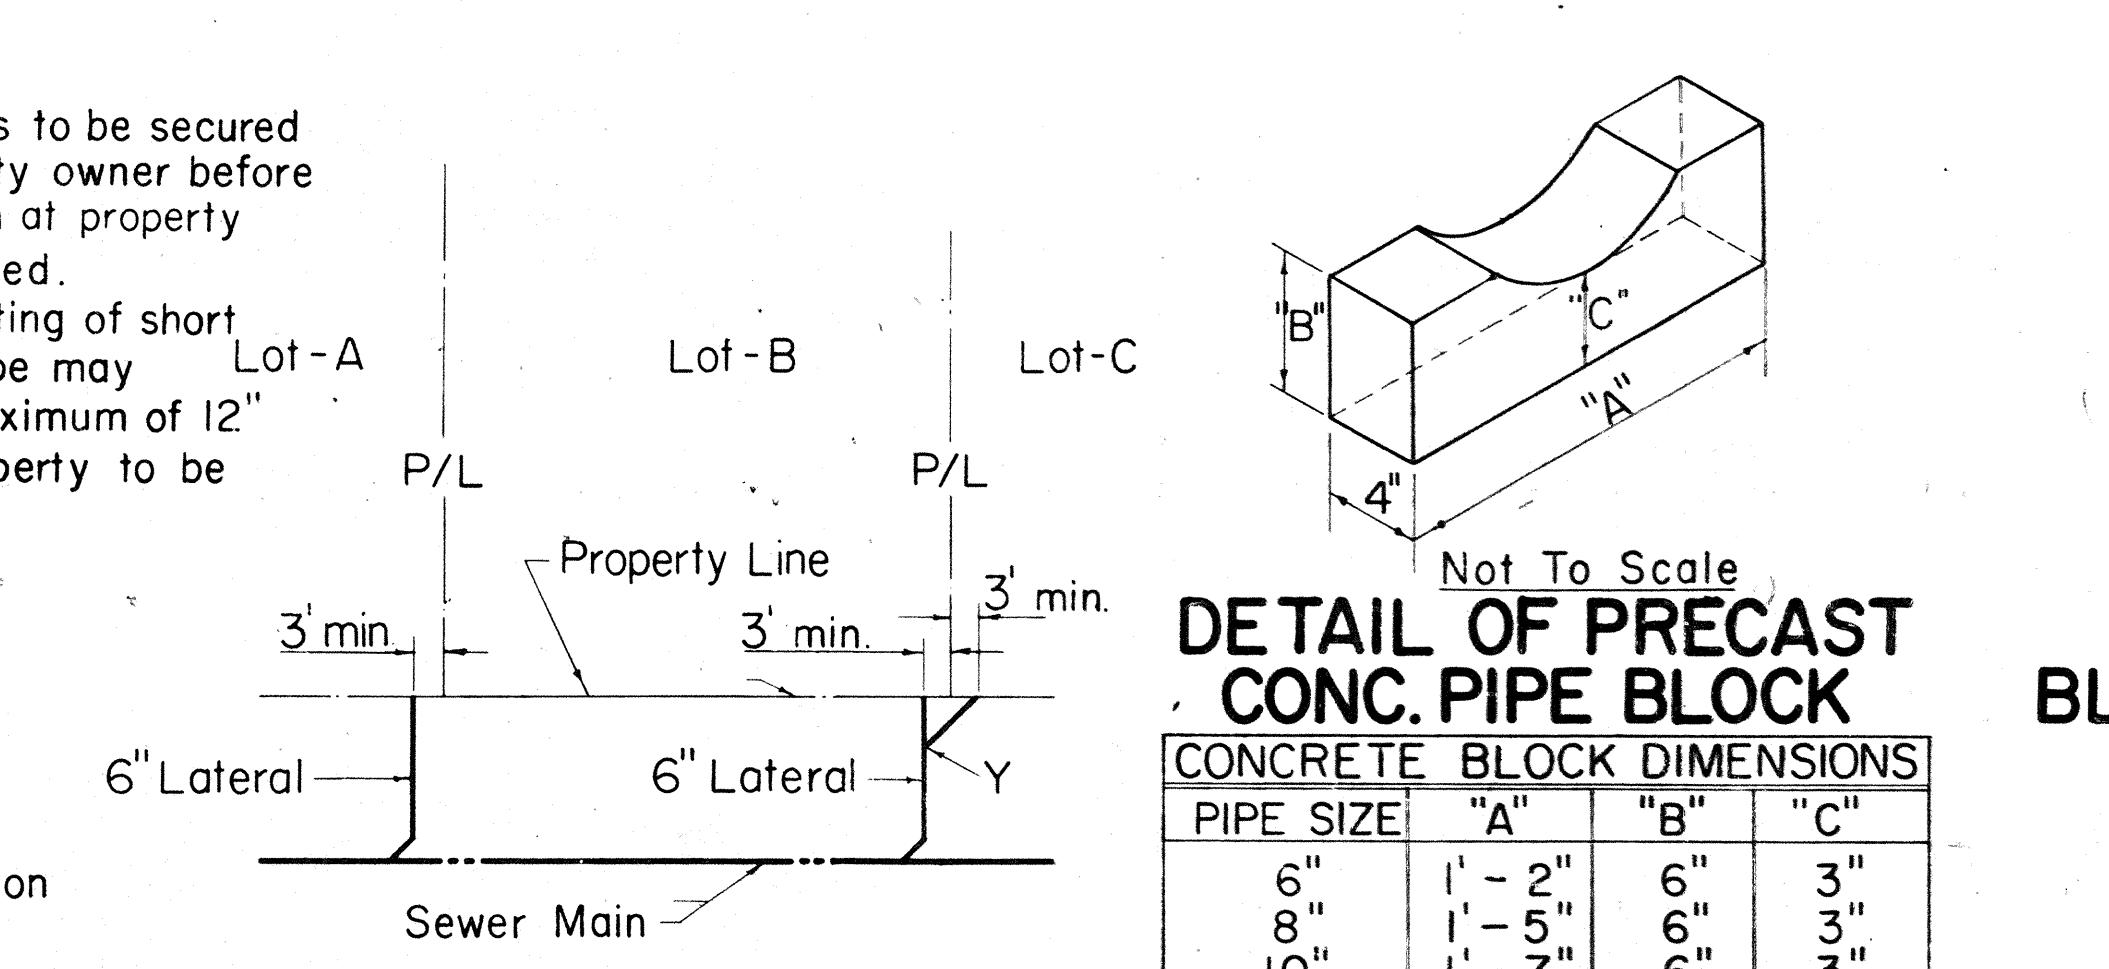


LAYOUT

DETAIL OF PRECAST CONCRETE PIPE BLOCK


PIPE SIZE	"A"	"B"	"C"
6"	1'-2"	6"	3"
8"	1'-5"	6"	3"
10"	1'-7"	6"	3"
12"	1'-7"	6"	3"
15"	1'-8"	6"	4"
18"	1'-9"	6"	4"
21"	1'-10"	6"	4"
24"	1'-11"	6"	4"
27"	2'-0"	6"	4"
30"	2'-3"	6"	4"

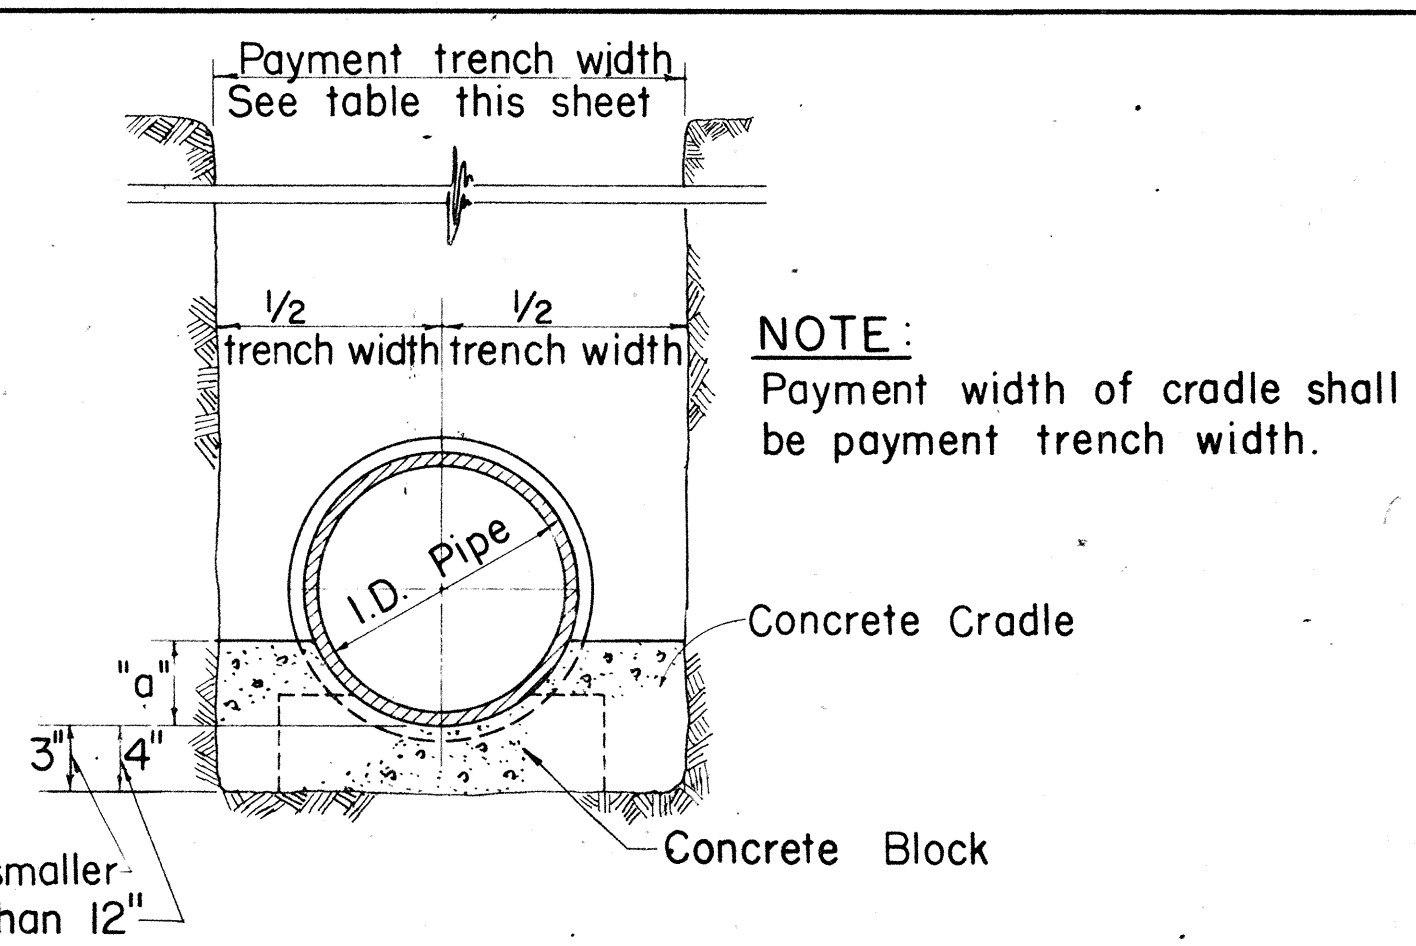


CONCRETE CRADLE FOR VITRIFIED CLAY PIPE
Not To Scale

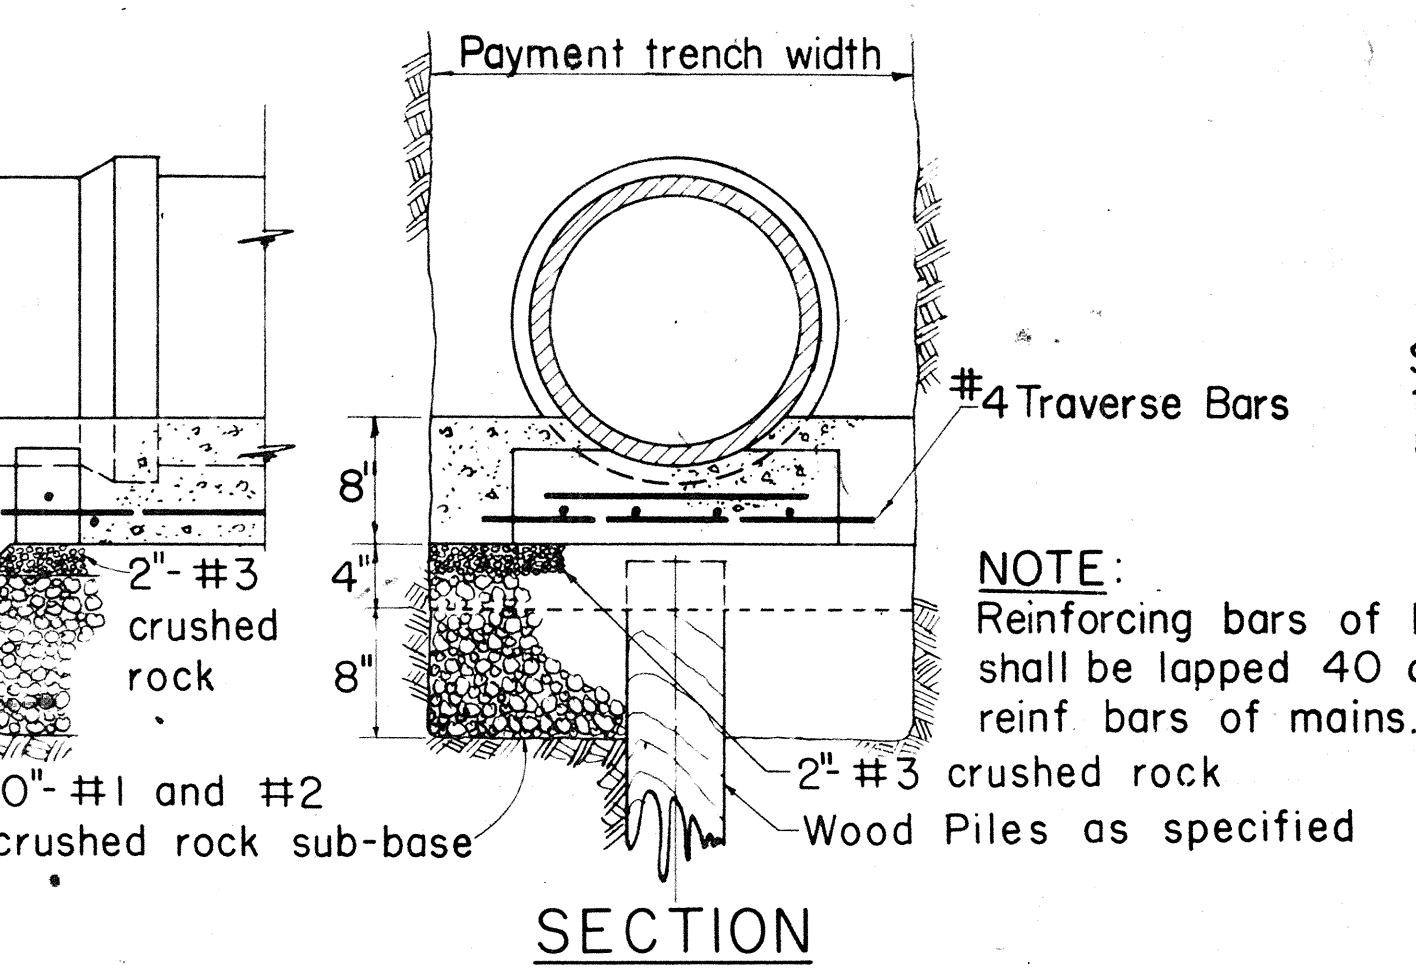



SECTION

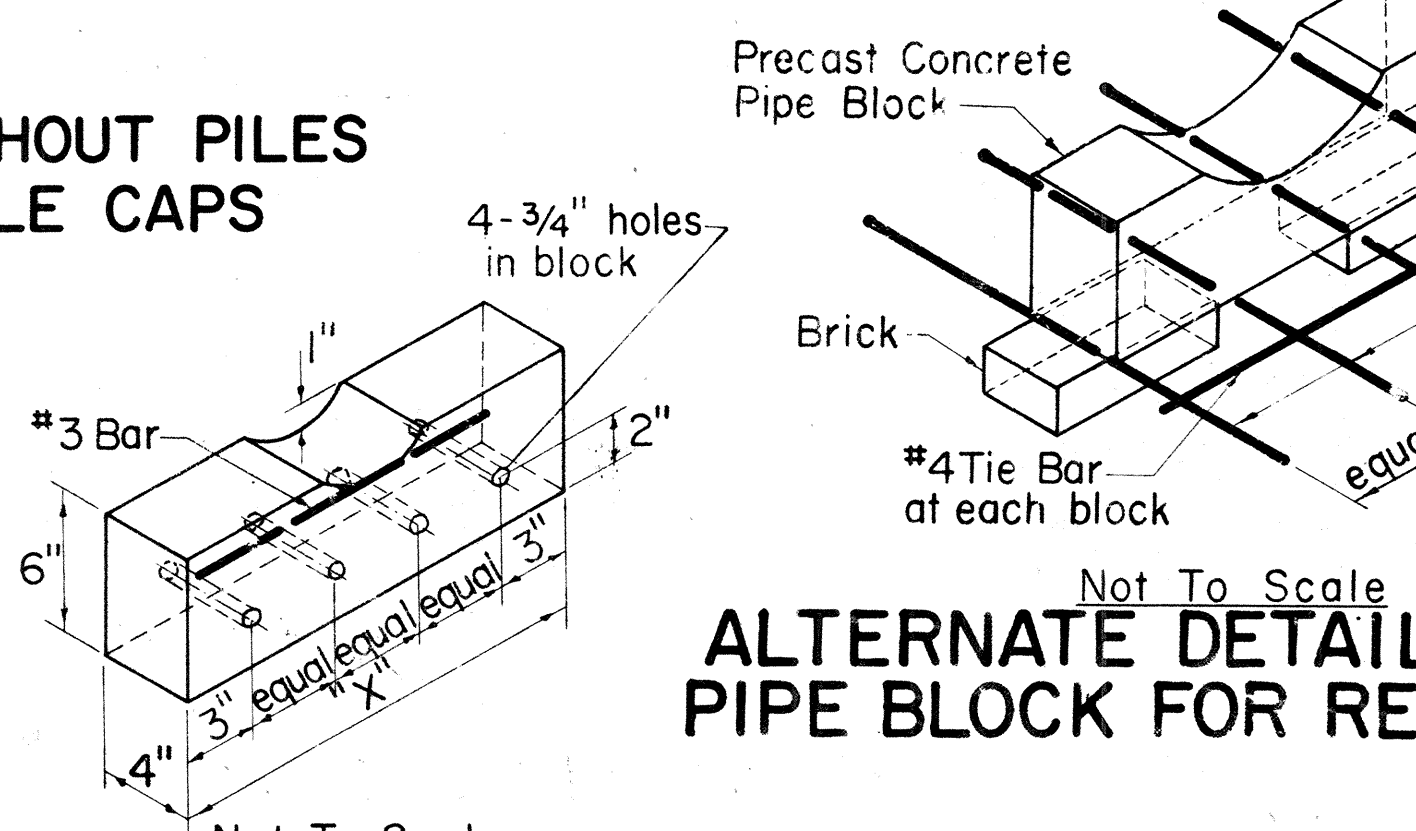

DETAIL OF CONC. PIPE BLOCK FOR REINF. CRADLE
Not To Scale

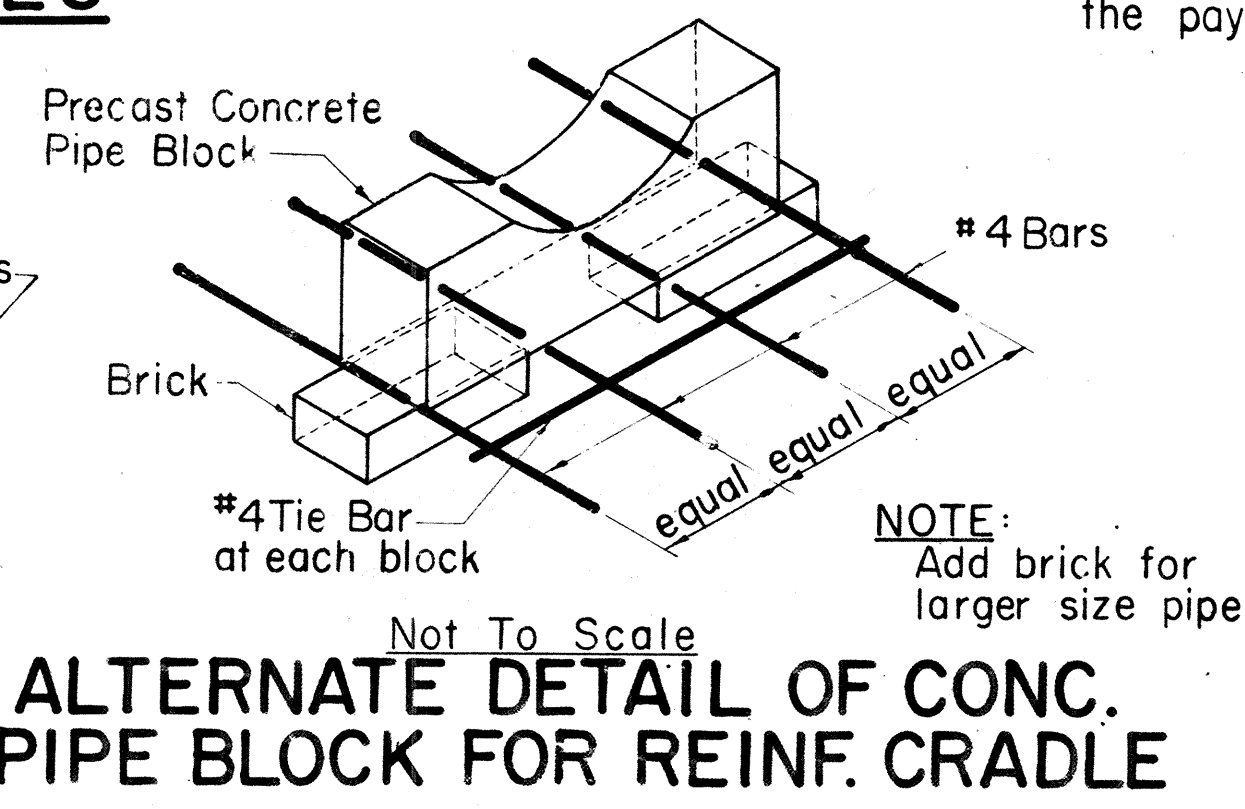

ALTERNATE DETAIL OF CONC. PIPE BLOCK FOR REINF. CRADLE
Not To Scale

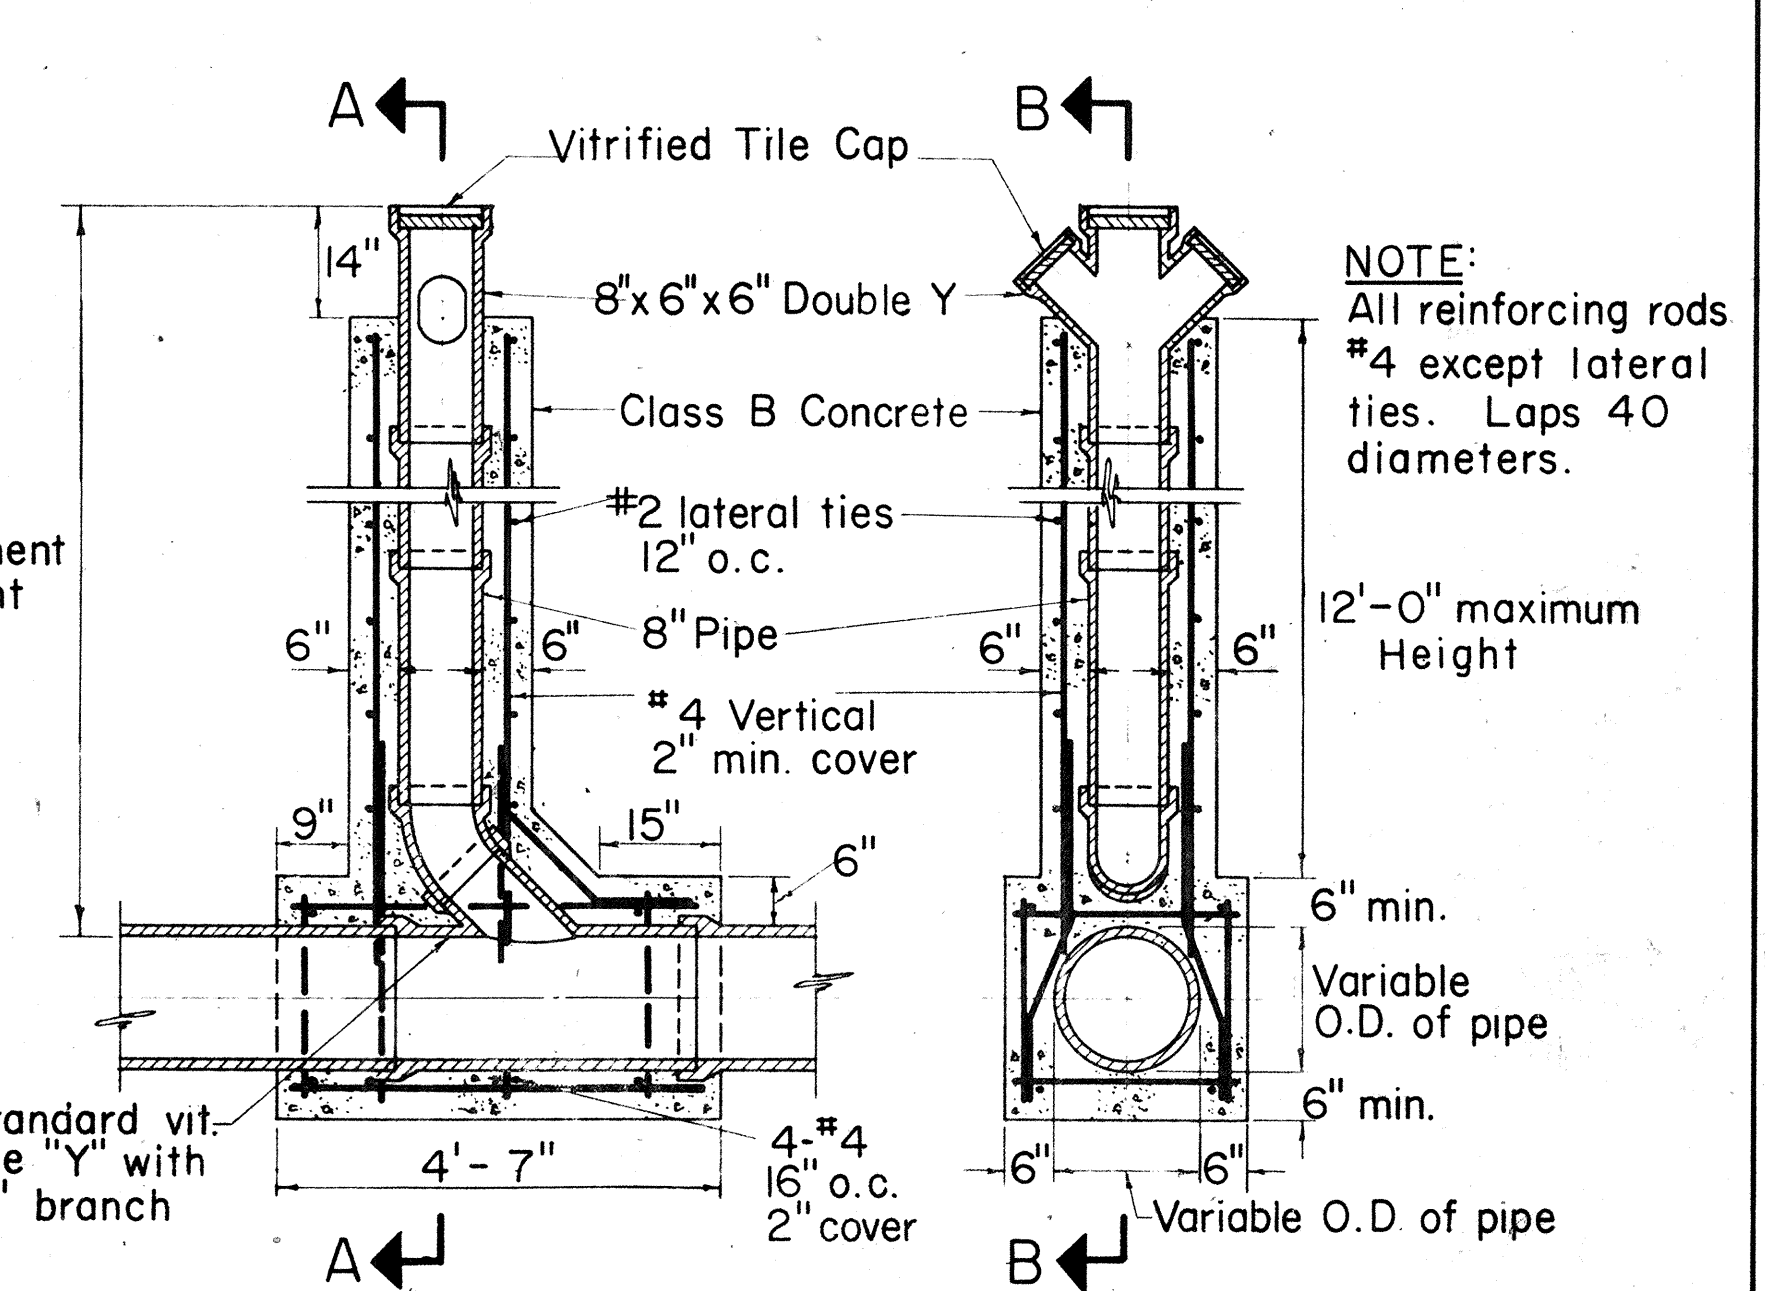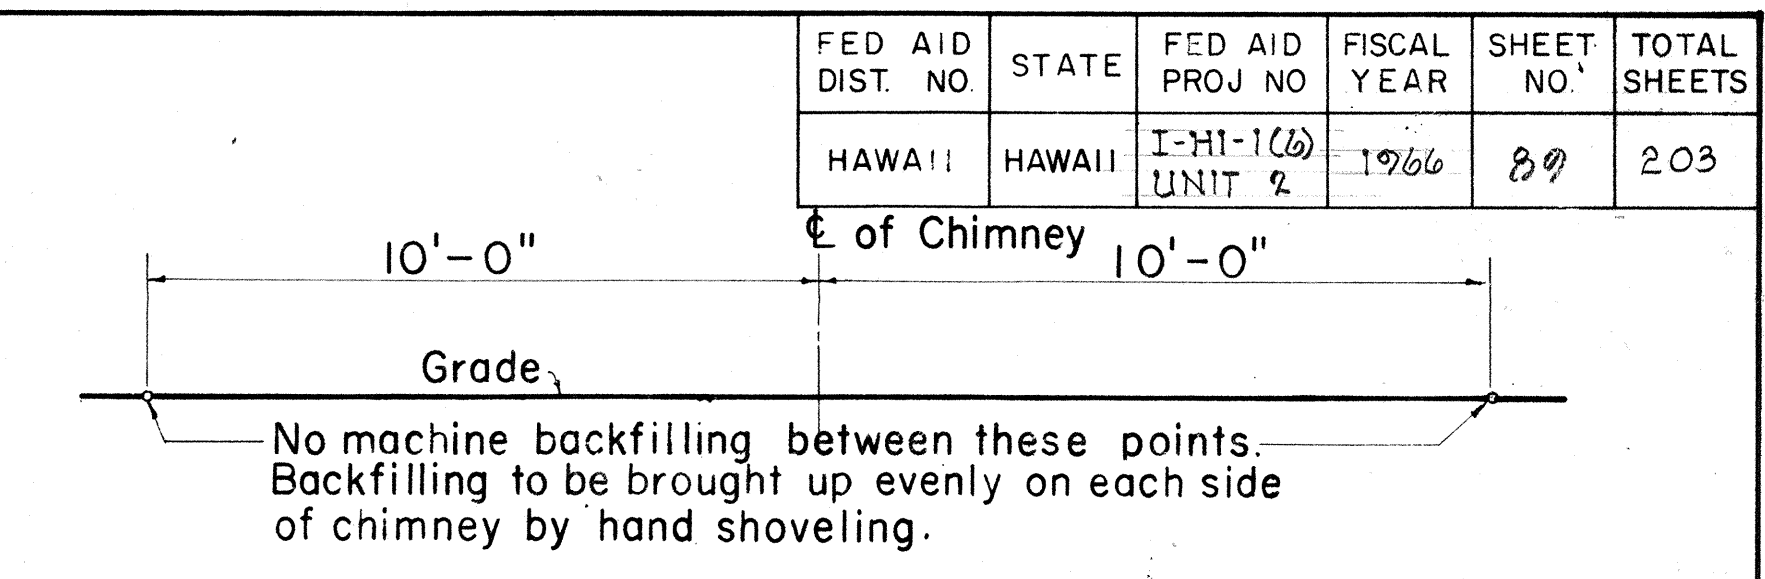

SECTION B-B SECTION A-A
DETAILS OF CHIMNEY
Scale: 1/2" = 1'-0"

Payment quantities for trench excavation, crushed rock fill, crushed rock cradle, and crushed rock sub-base shall be computed using payment trench widths as shown in the table of "Trench Widths". No payment shall be made for excess quantities resulting from trench widths greater than the payment trench widths shown.

VITRIFIED CLAY PIPE TABLE

TRENCH WIDTHS		DIM. OF CONC. CRADLE	
PIPE SIZE	PAY. WIDTH	PIPE SIZE	"a" WIDTH
6"	24"	6"	3"
8"	24"	8"	3"
10"	24"	10"	3"
12"	30"	12"	3"
15"	38"	15"	4"
18"	41"	18"	5"
21"	45"	21"	5"
24"	50"	24"	6"
27"	53"	27"	7"
30"	57"	30"	7"

APPROVED: *[Signature]*
SEWER SYSTEM/DIRECTOR,
DIVISION OF SEWERS
DATE: 12-2-65

STATE OF HAWAII
DEPARTMENT OF TRANSPORTATION
HIGHWAYS DIVISION
DIVISION OF SEWERS
CITY & COUNTY OF HONOLULU

STANDARD DETAILS
SEWERS-CONCRETE JACKET & MISCELLANEOUS DETAILS
INTERSTATE HIGHWAY (LUNALILO FREEWAY)
F.A.I. PROJ. NO. I-HI-1(6) UNIT 2
Scale: As Noted Date: NOVEMBER 1965

SHEET NO. 13 OF 13 SHEETS

Revised Oct. 1965