

FED. ROAD DIST. NO.	STATE	FED. AID PROJ. NO.	FISCAL YEAR	SHEET NO.	TOTAL SHEETS
HAWAII	HAW.	1-HI-1(64)12 UNIT 2 1-HI-1(64)11	1968	49	128

GENERAL WATER NOTES

- The Contractor shall notify the Board of Water Supply in writing one week prior to commencing work on the water system.
- The Contractor shall arrange with the Board of Water Supply to out-off existing unused service laterals, remove meter boxes and appurtenances, prior to commencement of clearing and grading operations. Contractor shall provide all necessary excavation.
- Asterisk (*) indicates work to be performed by BWS. Materials to be furnished by the Contractor unless specified as "relocate."
- All excavation and backfill shall be done by the Contractor, including excavation for the relocation and lowering of existing mains.
- The locations of existing water mains and appurtenances shown on the plans are approximate only and the Contractor shall verify the exact locations. Any adjustment to the water mains and appurtenances whether shown on the construction plans or not shall be made a part of the project.
- The Contractor shall plug the ends of abandoned water mains with class "C-1" concrete. Payment for class "C-1" concrete used as plugs shall be considered incidental to the various contract items for the water system.
- Concrete in reaction and test blocks and reinforced concrete jacket shall be Class B-1. Existing 36" Main is of Southern Pipe manufacture. The Contractor shall be responsible to furnish all necessary materials, including adaptors if required, to facilitate connections into existing mains. Cost of adaptors shall be incidental to Pipeline Work.
- H.E.Co. and H.T.Co. utility poles, handholes, manholes, ductlines and sewer mains and appurtenances to have minimum of three (3) feet clearance from water mains and other water system appurtenances. Ductlines and sewer lines crossing water mains to have minimum 6" vertical clearances.
- Extra precaution shall be taken when rolling over new or existing cast iron pipes. Any damage to pipes and appurtenances shall be the responsibility of the Contractor.
- Any excavation work around existing water main shall be by hand only.
~~All 36" concrete cylinder pipe shall be class 150 and manufactured in accordance with the requirements of Section 100, the Special Provisions and the Manufacturer's Detail Drawings and to be approved by B.H.S.~~
- All gate valves, fire hydrants and other appurtenances specified as "salvage" on the plans shall be removed, cleaned, and returned to B.W.S. Manana Store Yard, by the Contractor.
- ~~Degree of concrete cylinder bend, or length of adjacent pipes required at points of connection to the existing main shall be verified after exposure of the existing main prior to the start of construction work. Any resulting revisions required shall be done by the Contractor at his own cost. Degree of concrete cylinder elbows specified on plan at connection points are for bidding purposes only.~~
- Temporary cleanouts shall be installed by the Contractor wherever necessary and the cost thereof shall be incidental to pipeline work.
- In fill areas where the cover (from the existing ground) over the new main is less than three (3) feet, the Contractor shall first fill and compact the area (to provide a minimum of three (3) feet cover) prior to trenching for the new main.
- B.W.S. shall make all taps to the existing mains for the connection of service laterals. The contractor shall perform all excavation and backfill and furnish appropriate sizes of corporation stops.

GENERAL SEWER NOTES

- The Engineer reserves the right to request the use of reinforced concrete cradle and jacket and or piling in the event that field conditions make such structural requirements necessary.
- The Contractor shall notify the Division of Sewers 2 days prior to commencement of sewer work.
- Top of sewer manholes in easements shall be four (4) inches above ground unless otherwise directed by the Engineer.
- Existing laterals shown are from best sources available. The Contractor shall verify the exact locations as required. Any other existing laterals exposed during construction shall be extended and reconnected to new mains if services are required or cut & plugged.
- All existing laterals to be reconnected shall be in accordance with "Typical House Sewer Connection Detail," sheet 62.
- All frames and covers on existing sewer manholes to be demolished shall be cleaned and reused on new sewer manholes.

GENERAL-ELECTRIC & TELEPHONE NOTES

- Existing electric and telephone systems shown on these plans are located from the best sources available. The Contractor shall check and verify the exact location and depth of same.
- Contractor to stake out proposed ductlines, pole and anchor locations; H.E.Co. to check locations before Contractor undertakes excavation.
- Minimum depth of duct lines from finish grade to top of concrete jacket where ducts are concrete encased = 2'-0" unless otherwise shown.
- Ducts encased in concrete jackets:
 - Normal distance from face of jacket to all ducts to be 3" minimum.
 - Clear distance of 1/2" minimum between ducts of same utility company.
 - Clear distances of 3" minimum between H.E.Co. ducts and H.T.Co. ducts.
- All ducts and conduits called for installation in concrete jacket shall be inspected and approved by the respective Engineer of H.E.Co. or H.T.Co. or their representative before concrete placing. 72 hr. (min.) notice shall be given before placing concrete.
- Depth of all pullboxes, service boxes, handholes and manholes to be determined in the field.
- Poles and anchors for H.E.Co. unless otherwise noted.
- Depth of poles and anchor holes are taken from finish grade.
- For pole setting depth data, see Sht. No. 62.
- Installation of, and backfill for poles by H.E.Co. unless otherwise noted.
- Backfill of anchor holes by the Contractor under H.E. Co. supervision unless otherwise noted.

GENERAL GAS NOTES

- All work required for the installation of the gas main facilities on the Aiea Hts. Separation Structure shall be done by Honolulu Gas Co. personnel and shall not be a part of this contract.
- The Contractor shall notify the Honolulu Gas Co. Ltd. at least 10 calendar days in advance of the bridge construction operations and shall coordinate his work with the Gas Co.

LEGEND

EXISTING

— S8 —
— W8 —
— G2 —
— E —
— T —
— SMH —
— WMH —
— GMH —
— W.V. —
— W.M. —
F.H. —
• P —
• L.S. —
• H.E. —
• H.T. —
X Pole —
— H —
— A.I.P. —
— H —

NEW

— S8 —
— W8 —
— G2 —
— E —
— T —
— SMH —
— WMH —
— GMH —
— W.V. —
— W.M. —
F.H. —
• P —
• L.S. —
• H.E. —
• H.T. —
X Pole —
— H —
— A.I.P. —
— H —

Sewer Line
Water Line
Gas Line
Electric Duct Line
Telephone Duct Line
Sewer Manhole
Water Manhole
Gas Manhole
Water Valve
Water Meter
Fire Hydrant
Electric or Telephone Pole
Electric or Telephone Pole with Anchor
Light Standard
Electric Handhole or Manhole
Telephone Handhole or Manhole
Electric or Telephone Pole to be removed
Water Line (Remove, Clean, Paint and Reinstall)
Cut and Plug Sewer, Water or Gas Line
Cut, Plug and Abandon in Place Sewer, Water or Gas Line
Lateral (Sprinkler System)

APPROVED:

G.D. Henderson
Hawaiian Electric Company, Inc.
R. J. Judd
Hawaiian Telephone Company
D. Kawakami
Chief Engineering Division, B.W.S.
W. J. Judd
Sewer System Director, Div. of Sewers

8-20-68
Date
8-20-68
Date
8/16/68
Date
8-17-68
Date



THIS WORK WAS PREPARED BY
ME OR UNDER MY SUPERVISION.

STATE OF HAWAII
DEPARTMENT OF TRANSPORTATION
HIGHWAYS DIVISION


UTILITY GENERAL NOTES SEWER, WATER, GAS, ELECTRIC AND TELEPHONE

INTERSTATE ROUTE H-1
PROJ. NO. 1-HI-1(16)11


Date: 8/16/68

SHEET No. 1 OF 27 SHEETS

FED. ROAD DIST. NO.	STATE	FED. AID PROJ. NO.	FISCAL YEAR	SHEET NO.	TOTAL SHEETS
HAWAII	HAW.	I-HI-1(64):12 UNIT 2	1969	50	128
		I-HI-1(6):11			

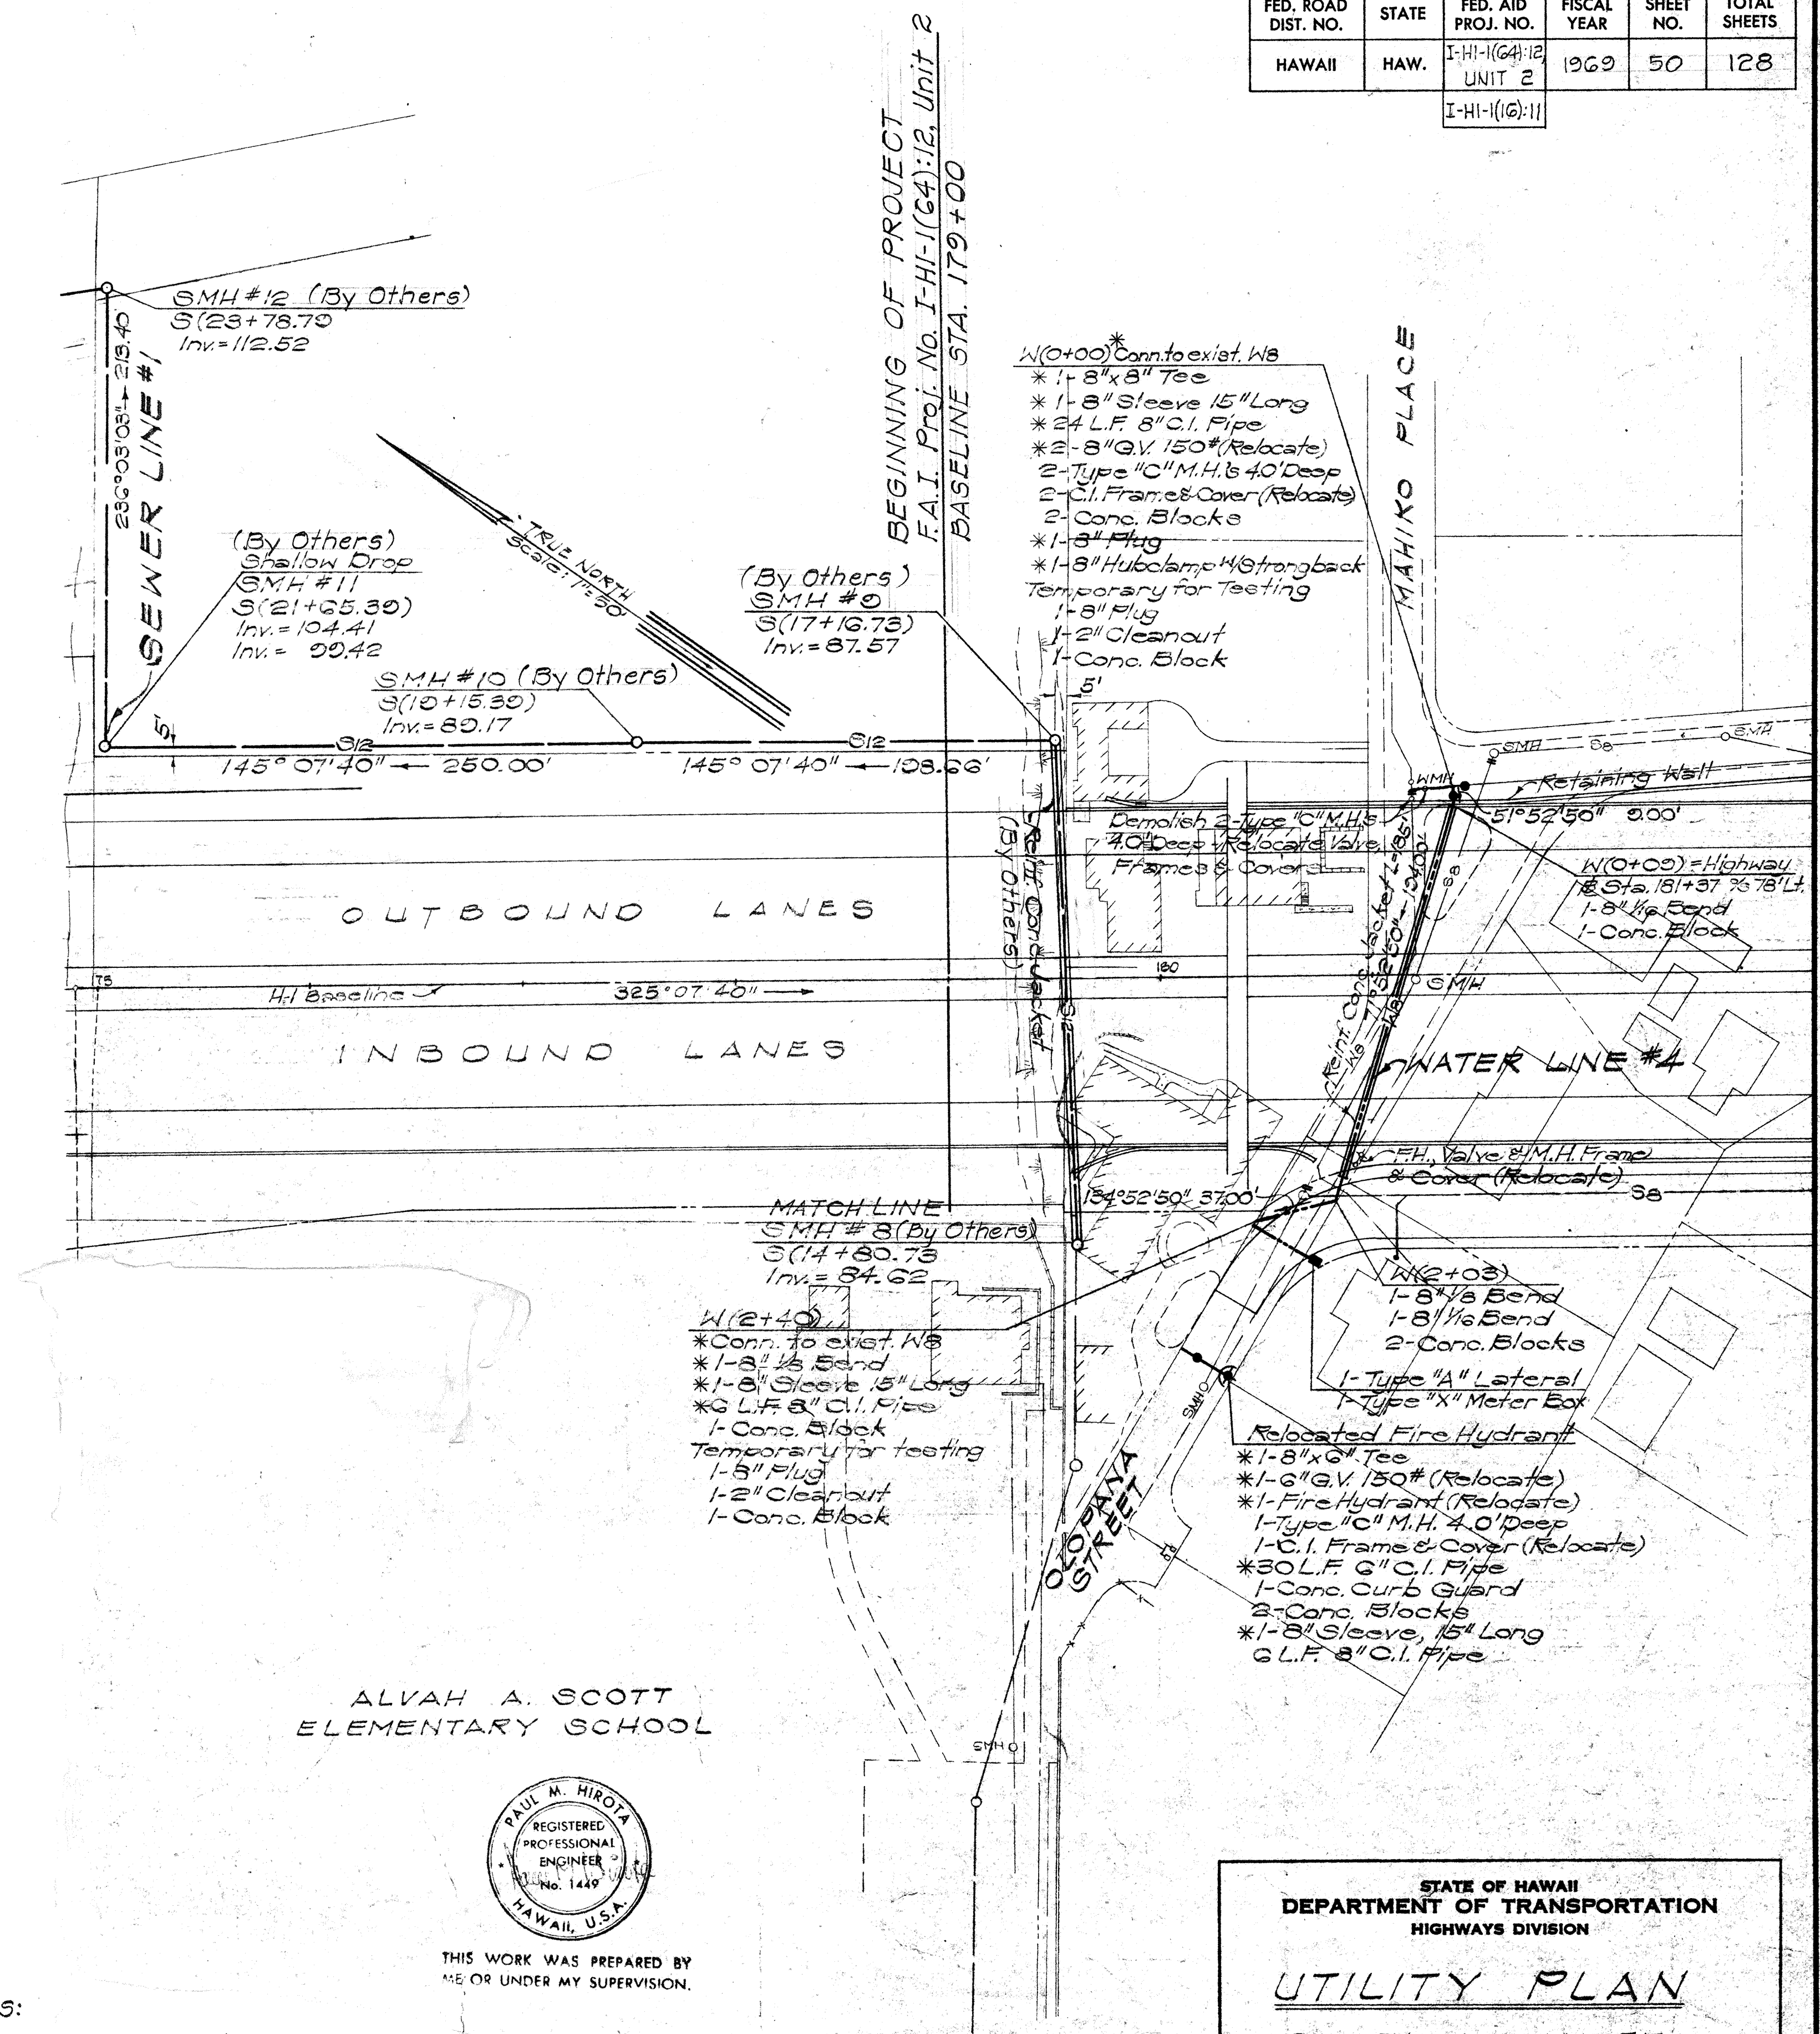

ALVAH A. SCOTT
ELEMENTARY SCHOOL

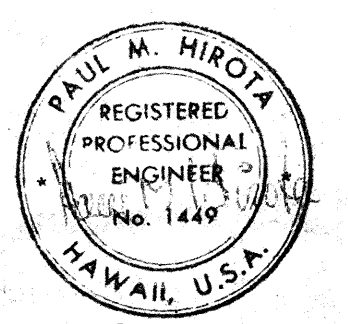

THIS WORK WAS PREPARED BY
ME OR UNDER MY SUPERVISION.

- REFERENCE NOTES:
1. For Water Line Profile, See Sht. 54.
 2. BWS to remove existing G gate valve and fire hydrant. Contractor to provide excavation, which shall be incidental to Rdwy. Exc.


APPROVED: *[Signature]* 8/17/68
General System Director, Date
Division of Sewers

APPROVED: *[Signature]* 8/1/68
Chief, Engineering Division Date
Board of Water Supply

STATE OF HAWAII
DEPARTMENT OF TRANSPORTATION
HIGHWAYS DIVISION

UTILITY PLAN
SEWER AND WATER
INTERSTATE ROUTE H-1
PROJ. NO. I-HI-1(6):11
Scale: 1"=50'-0" Date: 8/16/68
SHEET No. 2 OF 27 SHEETS

FED. ROAD DIST. NO.	STATE	FED. AID PROJ. NO.	FISCAL YEAR	SHEET NO.	TOTAL SHEETS
HAWAII	HAW.	I-H-1(64):12 Unit 2	1969	52	128

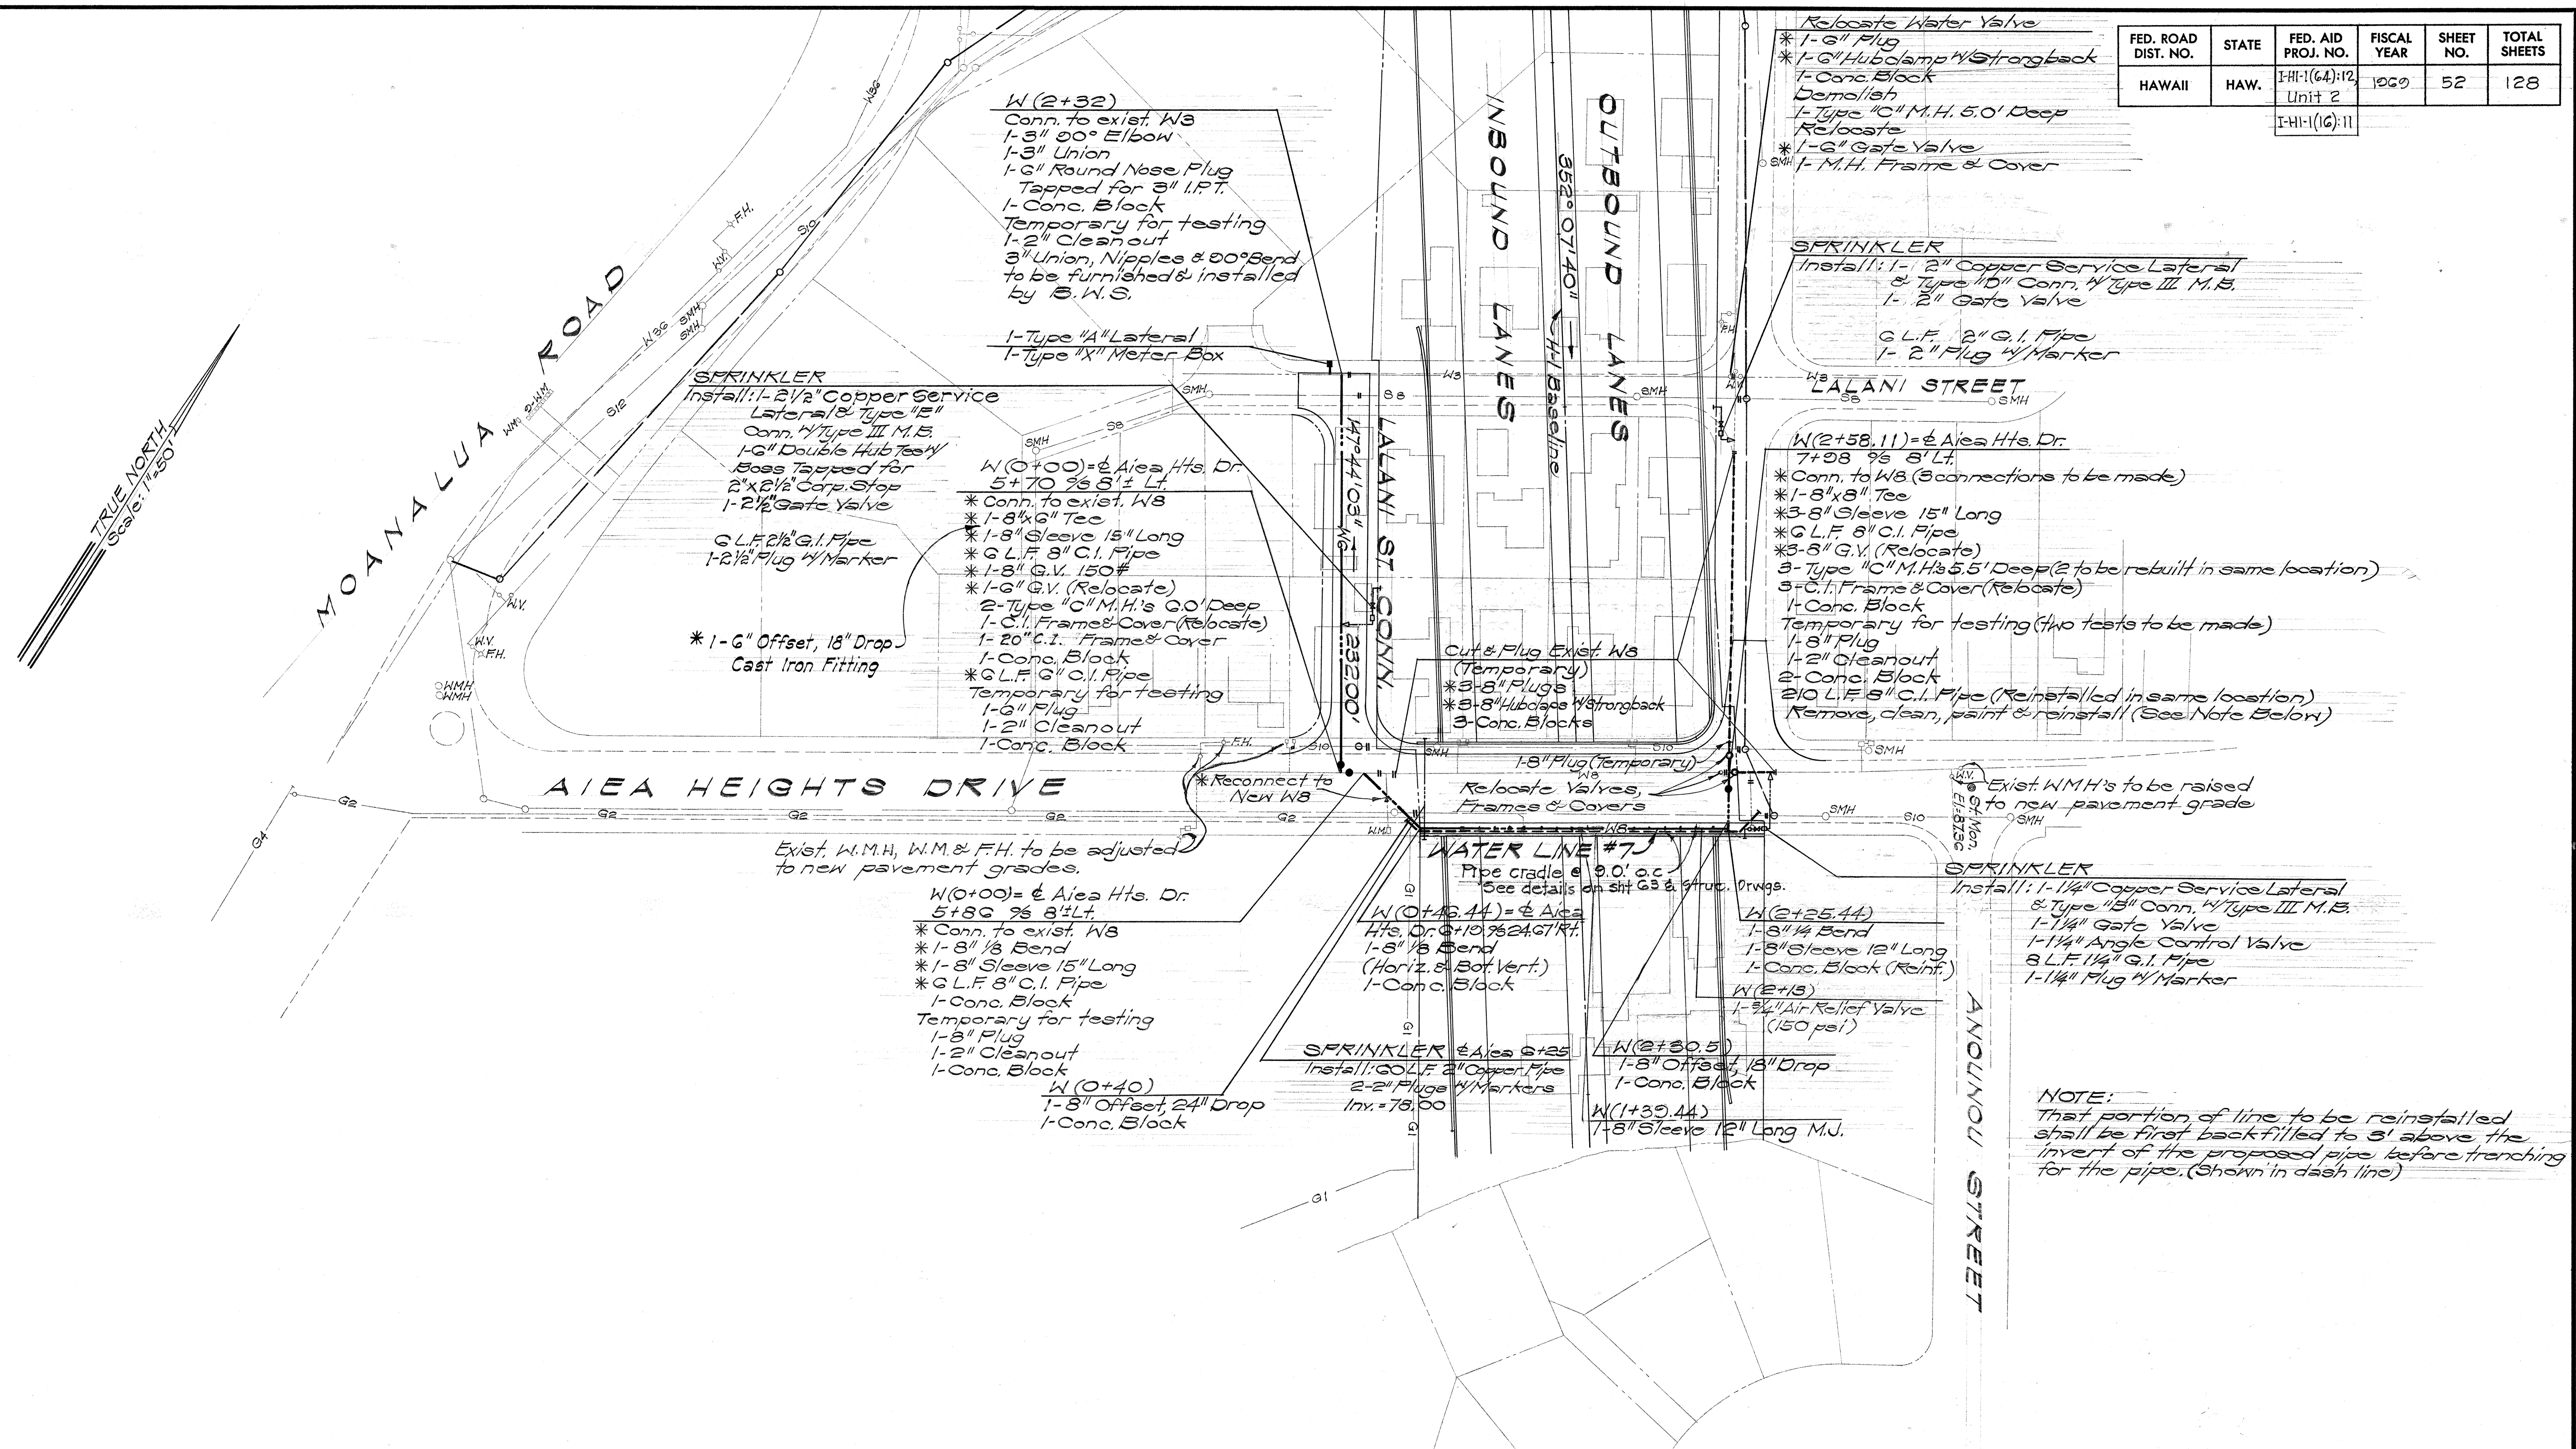

- NOTES:
1. For Water Line Profiles, See Sht. 54.
 2. The excavation to expose the 8" Gate Valves shall be incidental to Structure Excavation for Bridges and shall not be paid for separately.
 3. The excavation to expose the 6" Gate Valve shall be incidental to the excavation for the Retaining Walls and shall not be paid for separately.
 4. All gate Valve removal shall be by BWS.



THIS WORK WAS PREPARED BY
ME OR UNDER MY SUPERVISION

APPROVED: A. Hewelcom
Chief, Engineering Division
Board of Water Supply

**STATE OF HAWAII
DEPARTMENT OF TRANSPORTATION
HIGHWAYS DIVISION**

UTILITY PLAN


WATER

INTERSTATE ROUTE H-1
PROJ. NO. I-HI-1(16):11


Scale: 1"=50' Date: 8/16/68

SHEET No. 4 OF 27 SHEETS

FED. ROAD DIST. NO.	STATE	FED. AID PROJ. NO.	FISCAL YEAR	SHEET NO.	TOTAL SHEETS
HAWAII	HAW.	I-H-1(64):12 UNIT 2 I-H-1(16):11	1969	54	128

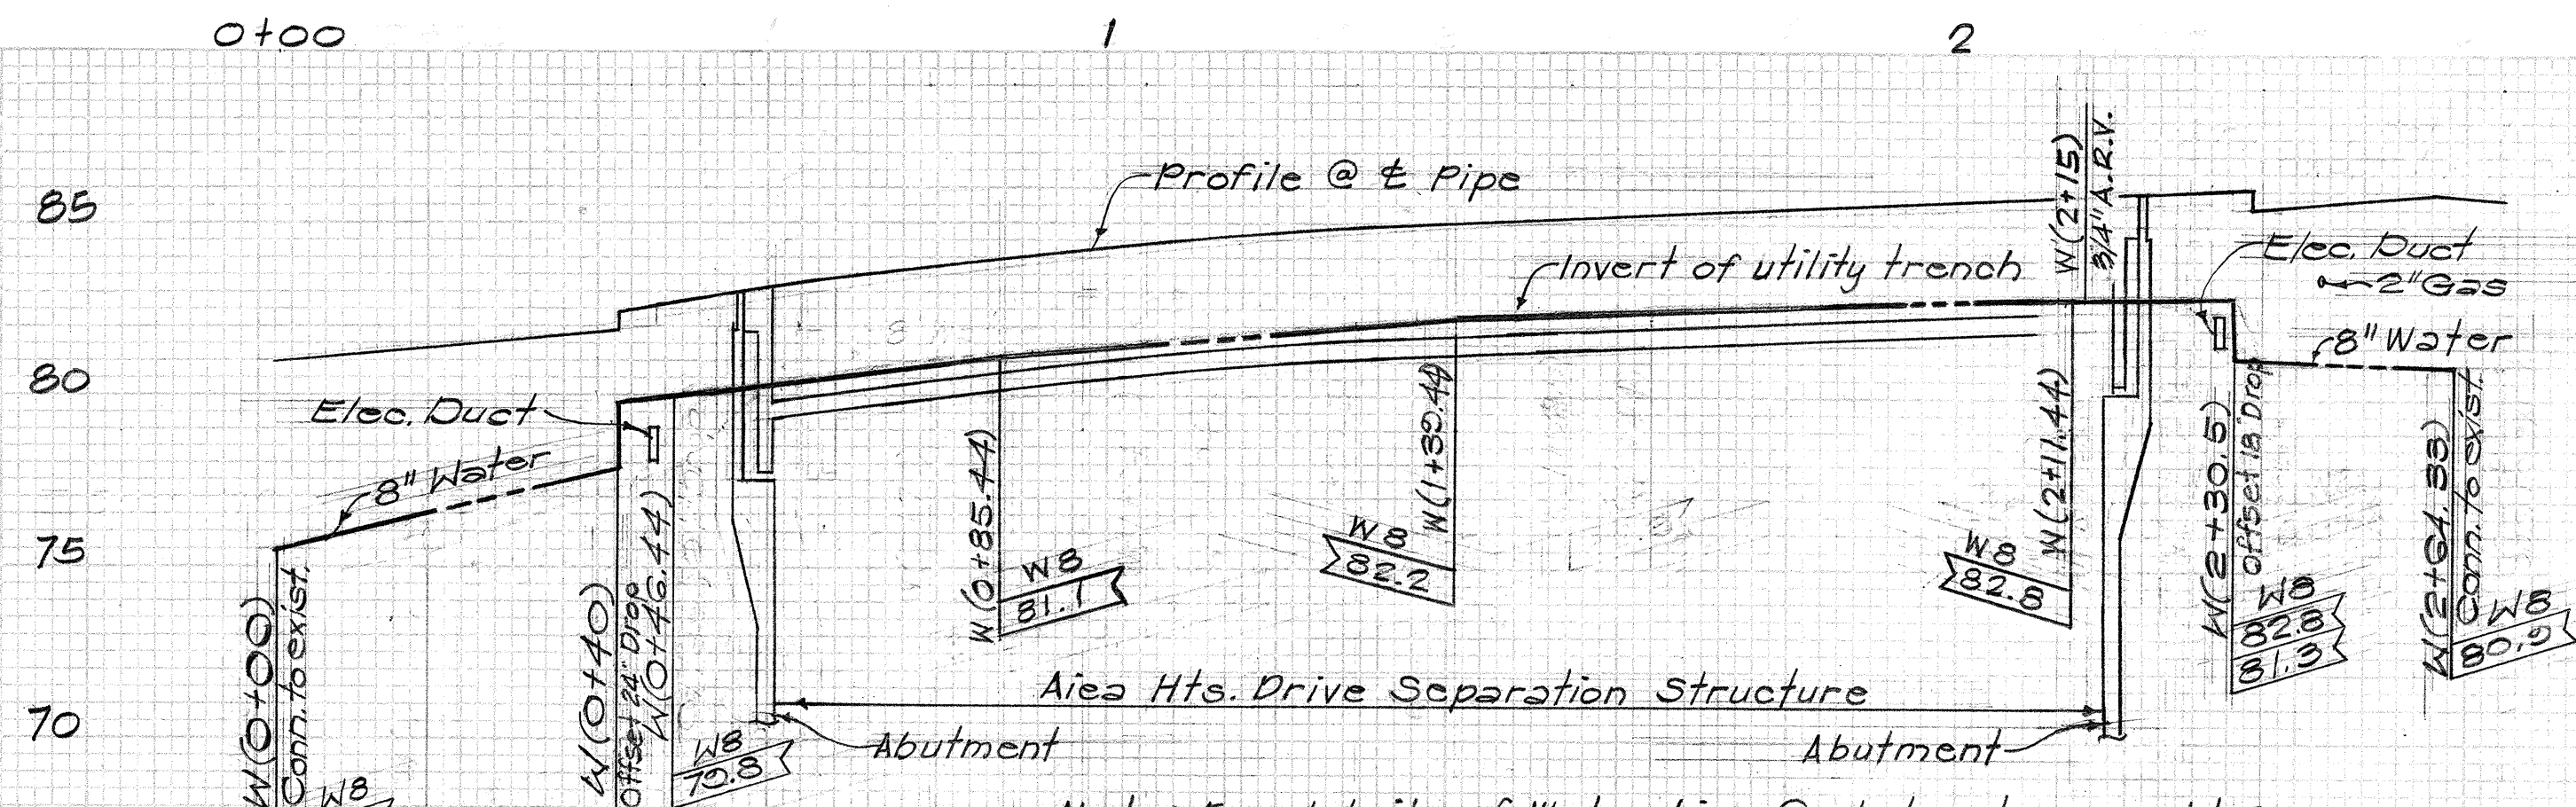


PROFILE - WATER LINE #7
(8" WATER LINE ON AIEA HTS. DR. SEPARATION STRUCTURE)
Scales: Horiz. 1" = 20'
Vert. 1" = 5'

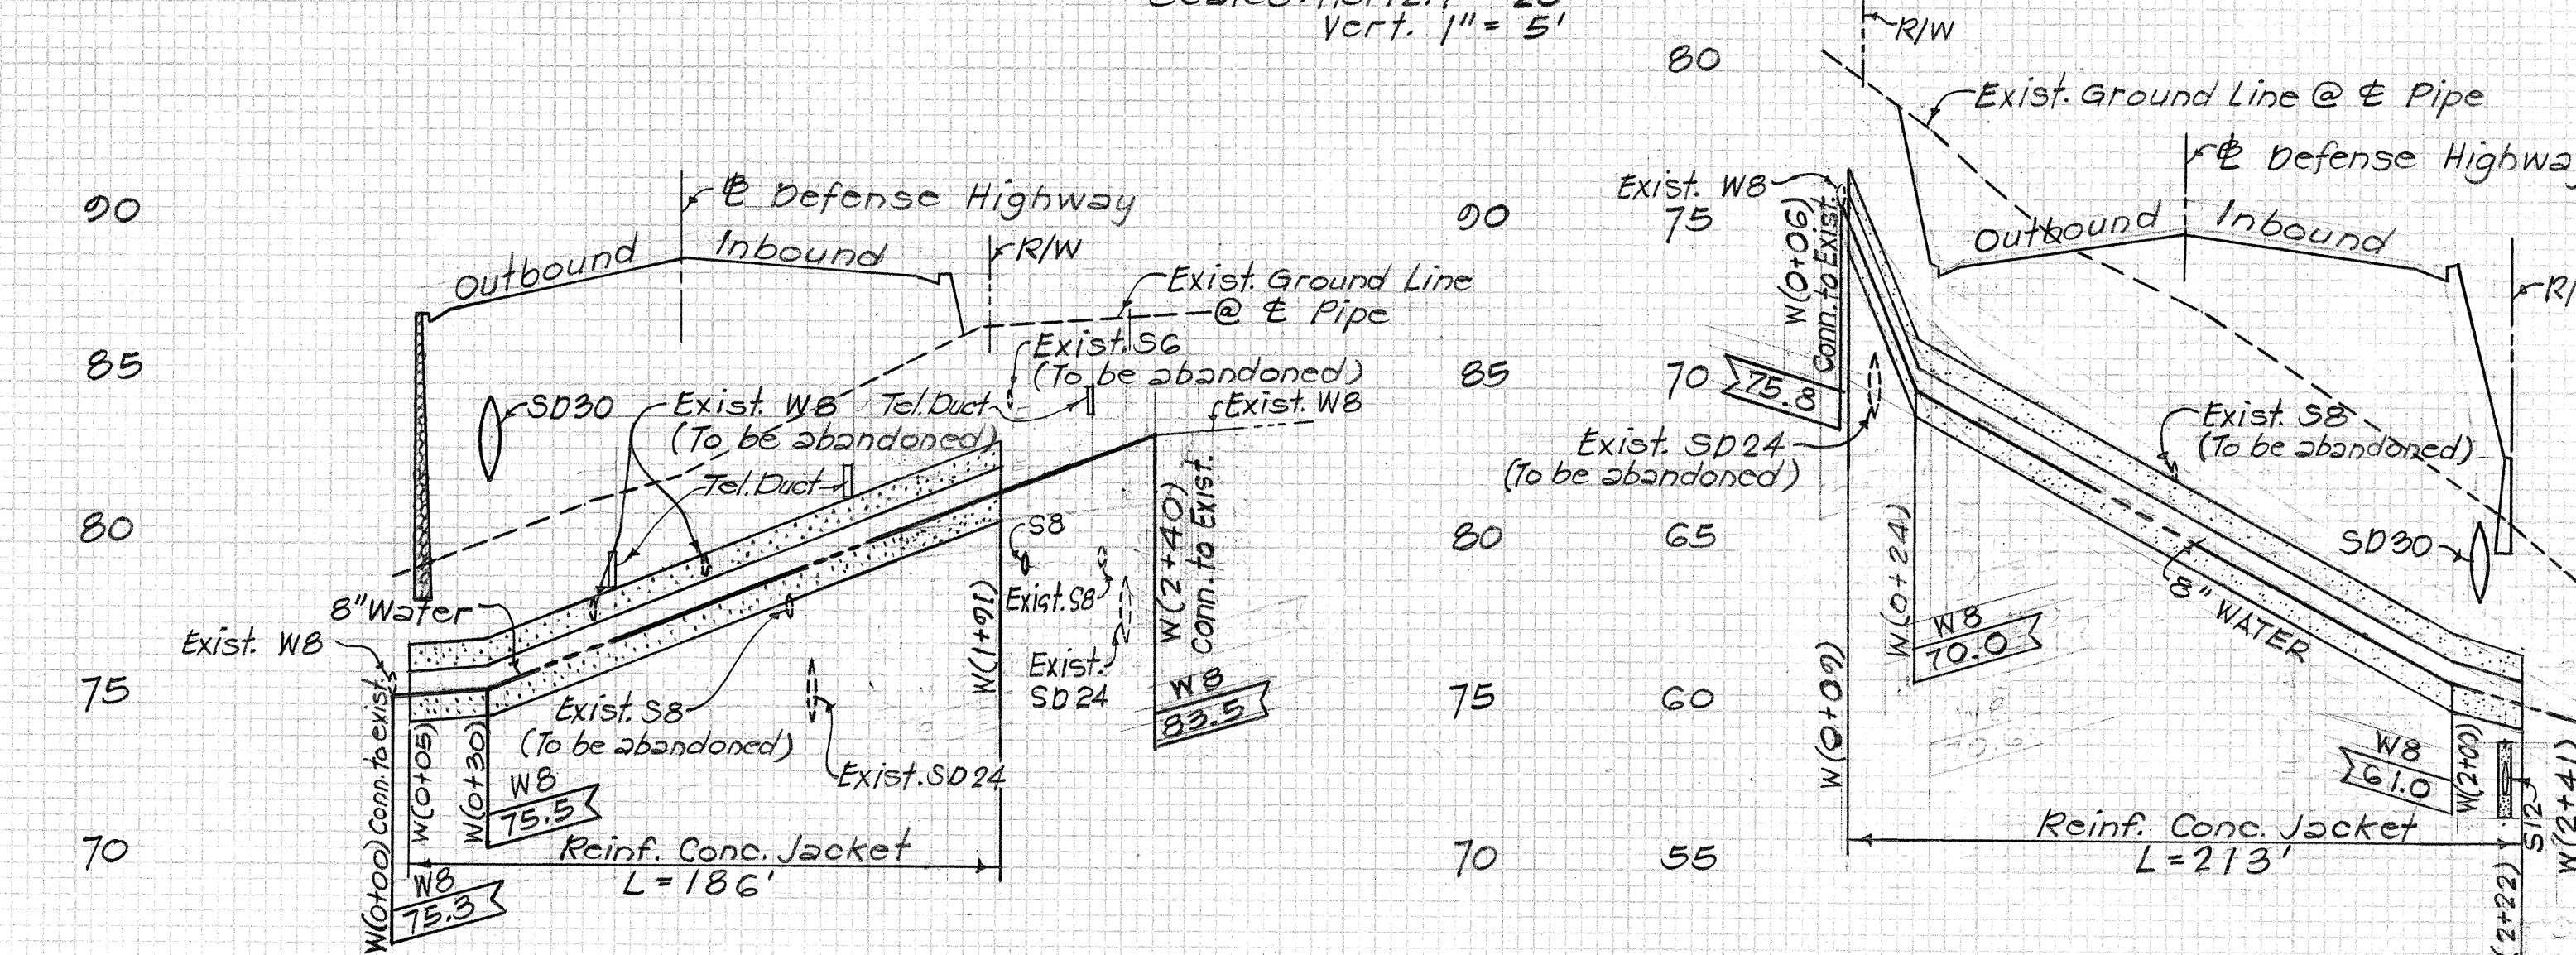


PROFILE - WATER LINE #4
(8" WATER LINE @ OLOPANA ST. EXTENSION)
Scales: Horiz. 1" = 50'
Vert. 1" = 5'


PROFILE - WATER LINE #5
(8" WATER LINE @ HELECONIA ST.)
Scales: Horiz. 1" = 50'
Vert. 1" = 5'

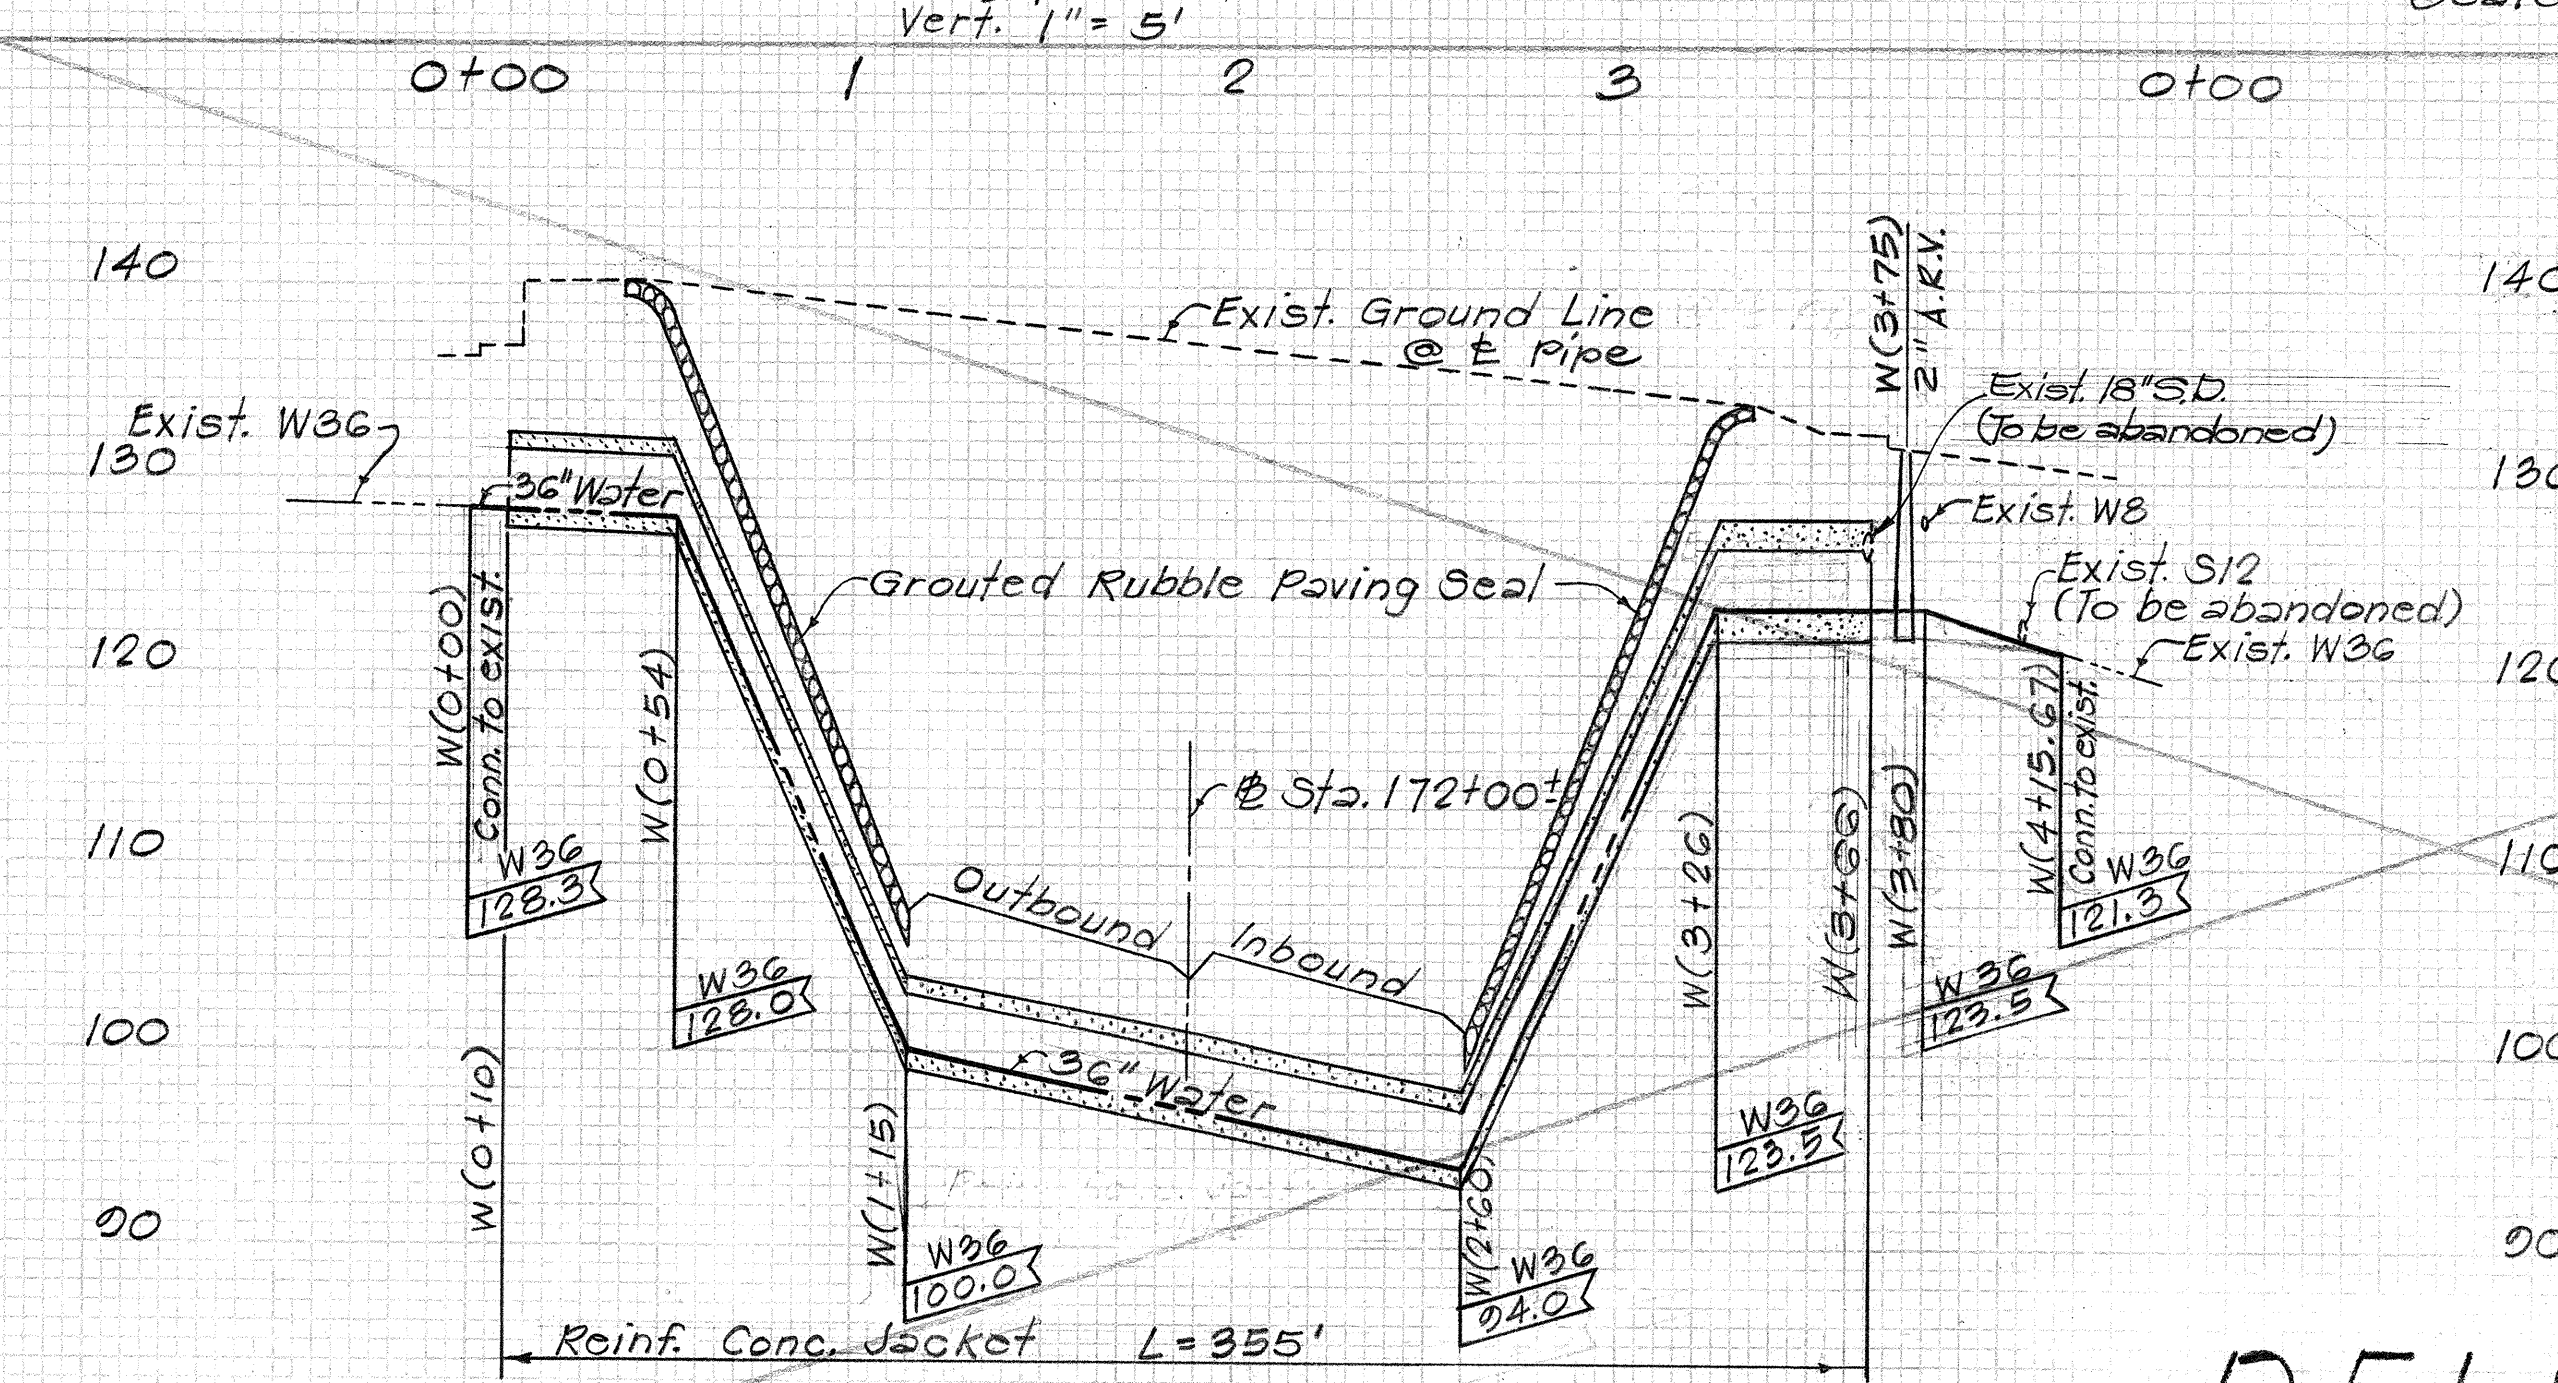


PROFILE - WATER LINE #2
(REALIGNED 36" WATER LINE @ KAAMILO ST.)
Scales: Horiz. 1" = 50'
Vert. 1" = 10'

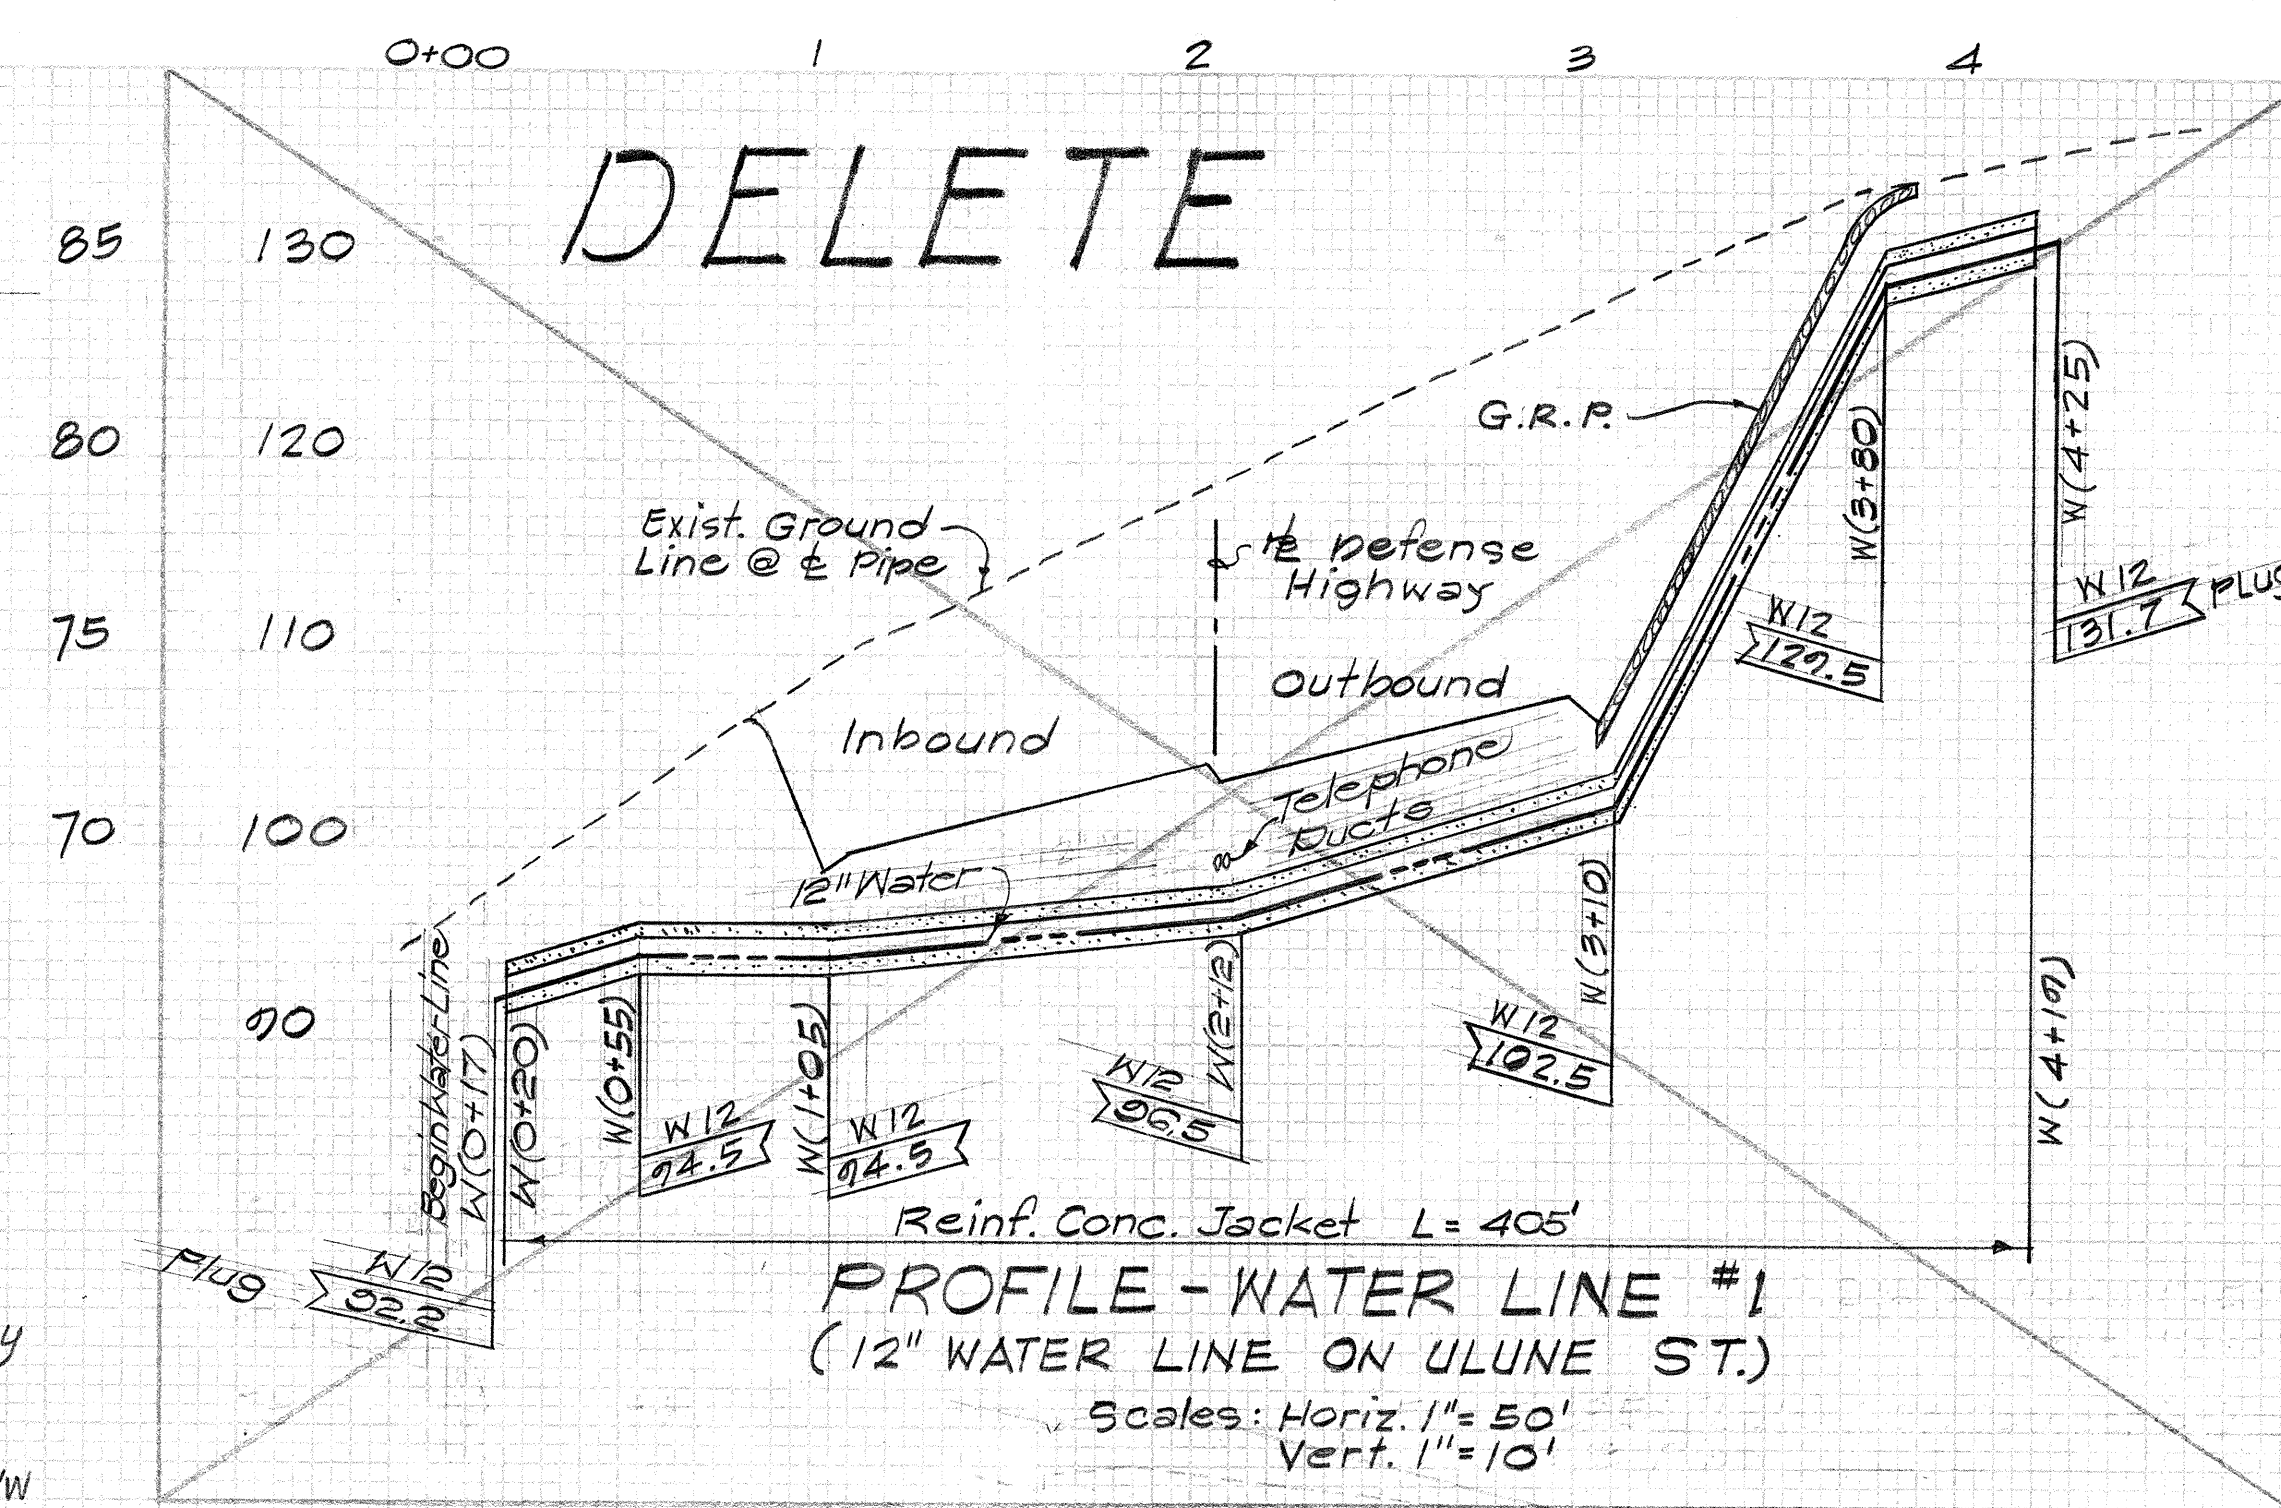

PROFILE - WATER LINE #1
(12" WATER LINE ON ULUNE ST.)
Scales: Horiz. 1" = 50'
Vert. 1" = 10'

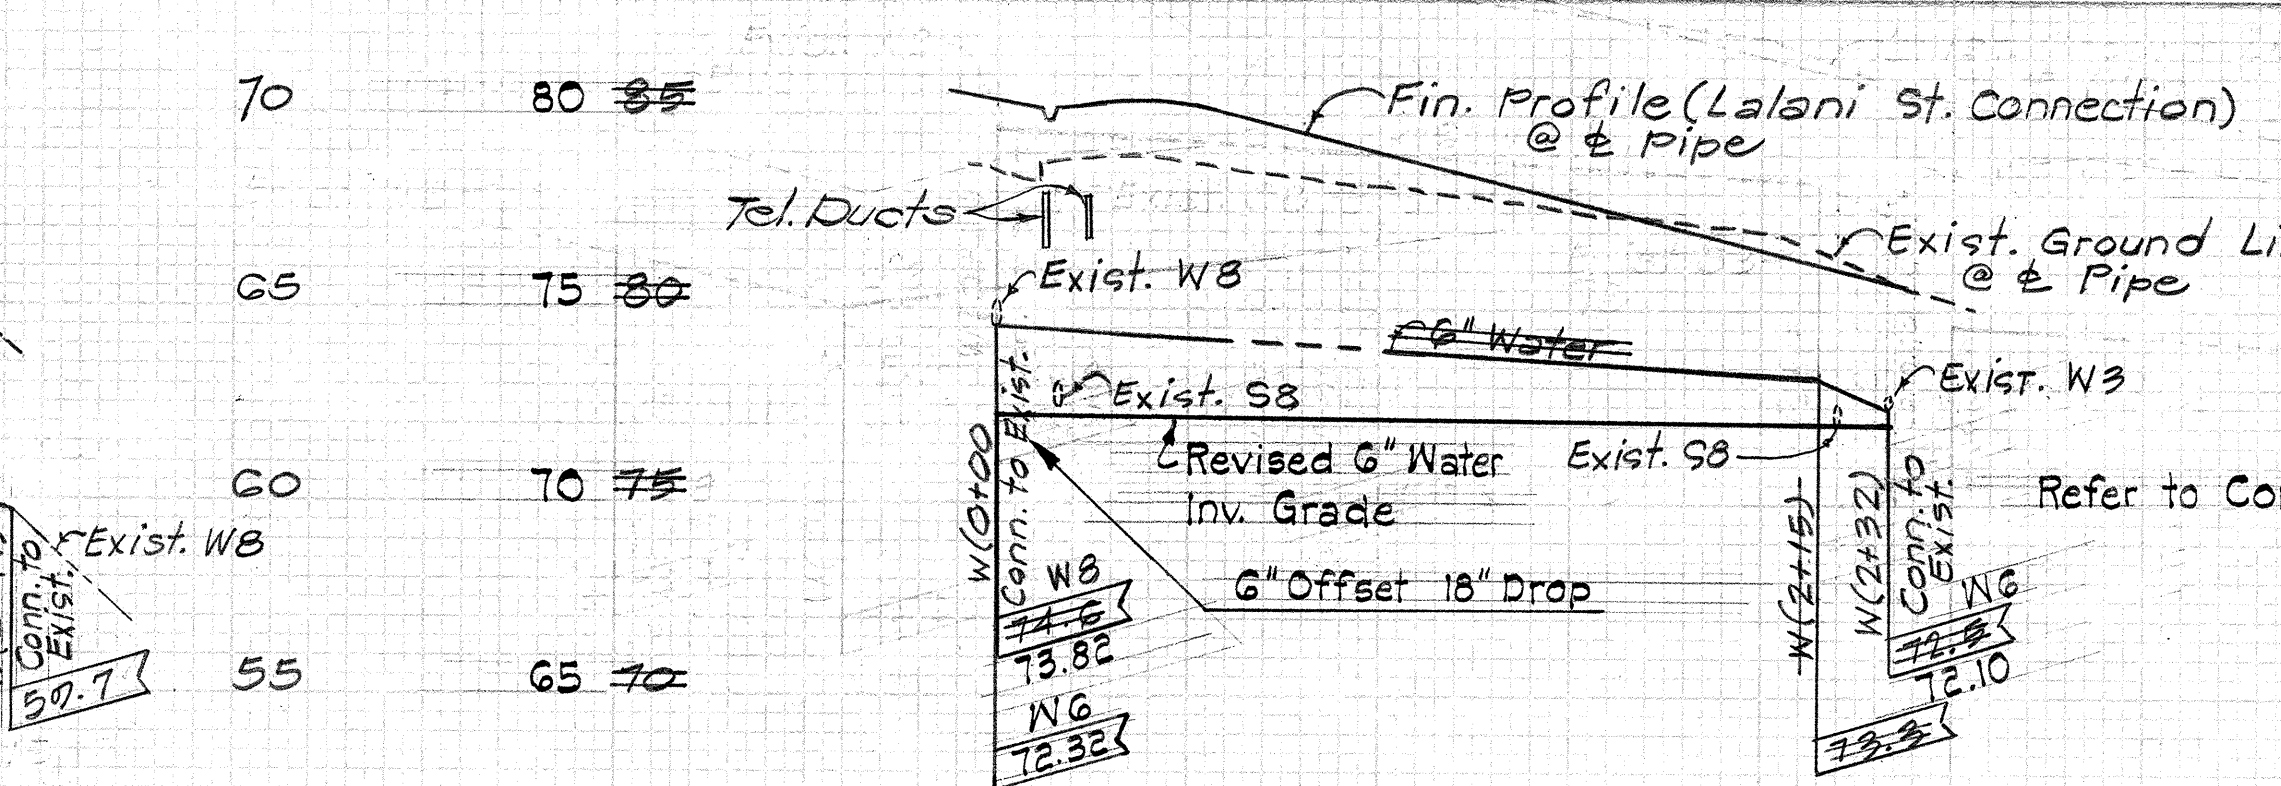


PROFILE - WATER LINE #6
(6" WATER LINE @ LALANI ST. CONN.)
Scales: Horiz. 1" = 50'
Vert. 1" = 5'

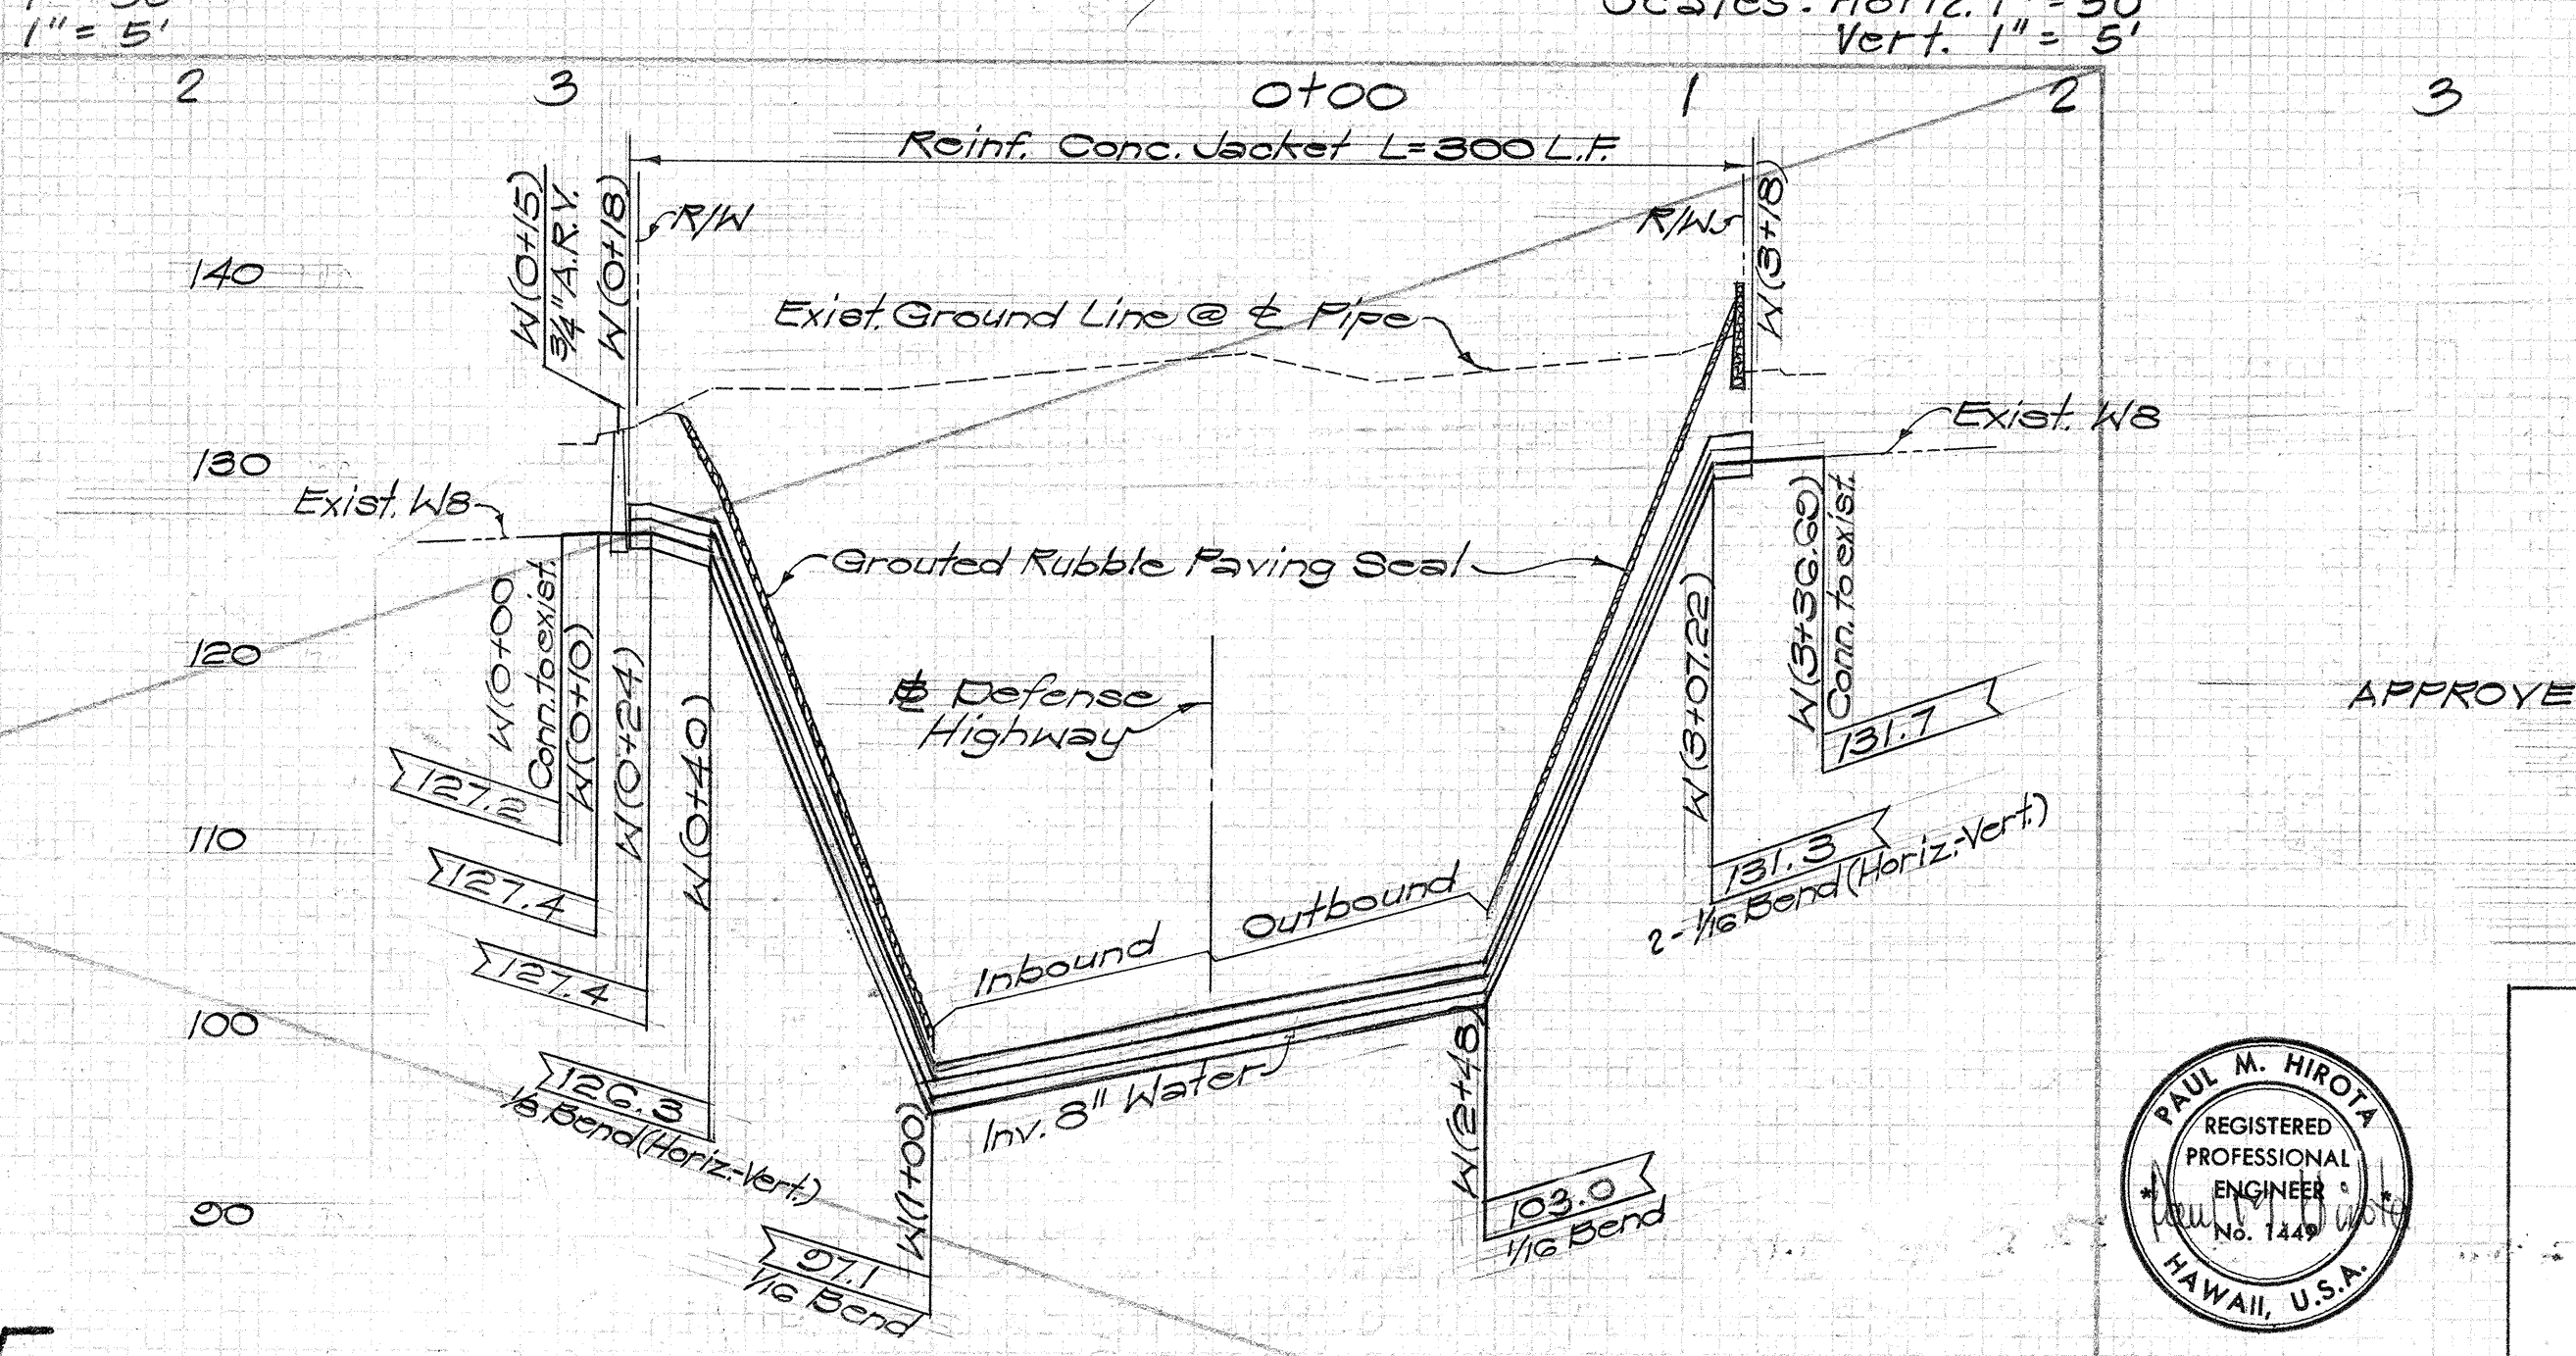

PROFILE - WATER LINE #3
(REALIGNED 8" WATER LINE @ KAAMILO ST.)
Scales: Horiz. 1" = 50'
Vert. 1" = 10'

APPROVED: *A. Kawakani* 8/1/68
Chief, Engineering Division
Board of Water Supply

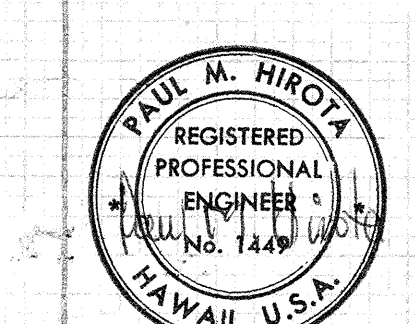

STATE OF HAWAII
DEPARTMENT OF TRANSPORTATION
HIGHWAYS DIVISION

UTILITY PROFILE
WATER


INTERSTATE ROUTE H-1
PROJ. NO. I-H-1(16):11

Scale: As Shown Date: 8/16/68


SHEET No. 6 OF 27 SHEETS

THIS WORK WAS PREPARED BY ME OR UNDER MY SUPERVISION.

Scales: Horiz. $1'' = 50'$
Vert. $1'' = 10'$

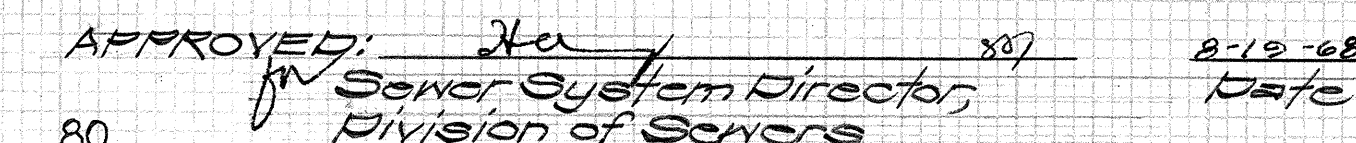

Scales: Horiz. $1'' = 50'$
Vert. $1'' = 10'$

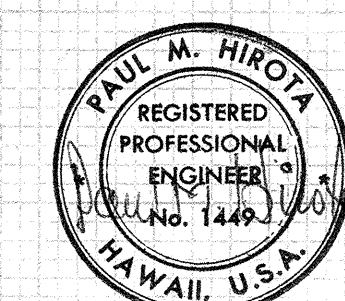

THIS WORK WAS PREPARED BY
ME OR UNDER MY SUPERVISION

STATE OF HAWAII
DEPARTMENT OF TRANSPORTATION
HIGHWAYS DIVISION


UTILITY PROFILE

SEWER



INTERSTATE ROUTE H-1
PROJ. NO. I-H1-1(16):11

Scale: As Shown - Date: 8/16/68
SHEET No. 7 OF 27 SHEETS


FED. ROAD DIST. NO.	STATE	FED. AID PROJ. NO.	FISCAL YEAR	SHEET NO.	TOTAL SHEETS
HAWAII	HAW.	I-HI-1(16):11	1969	56	128

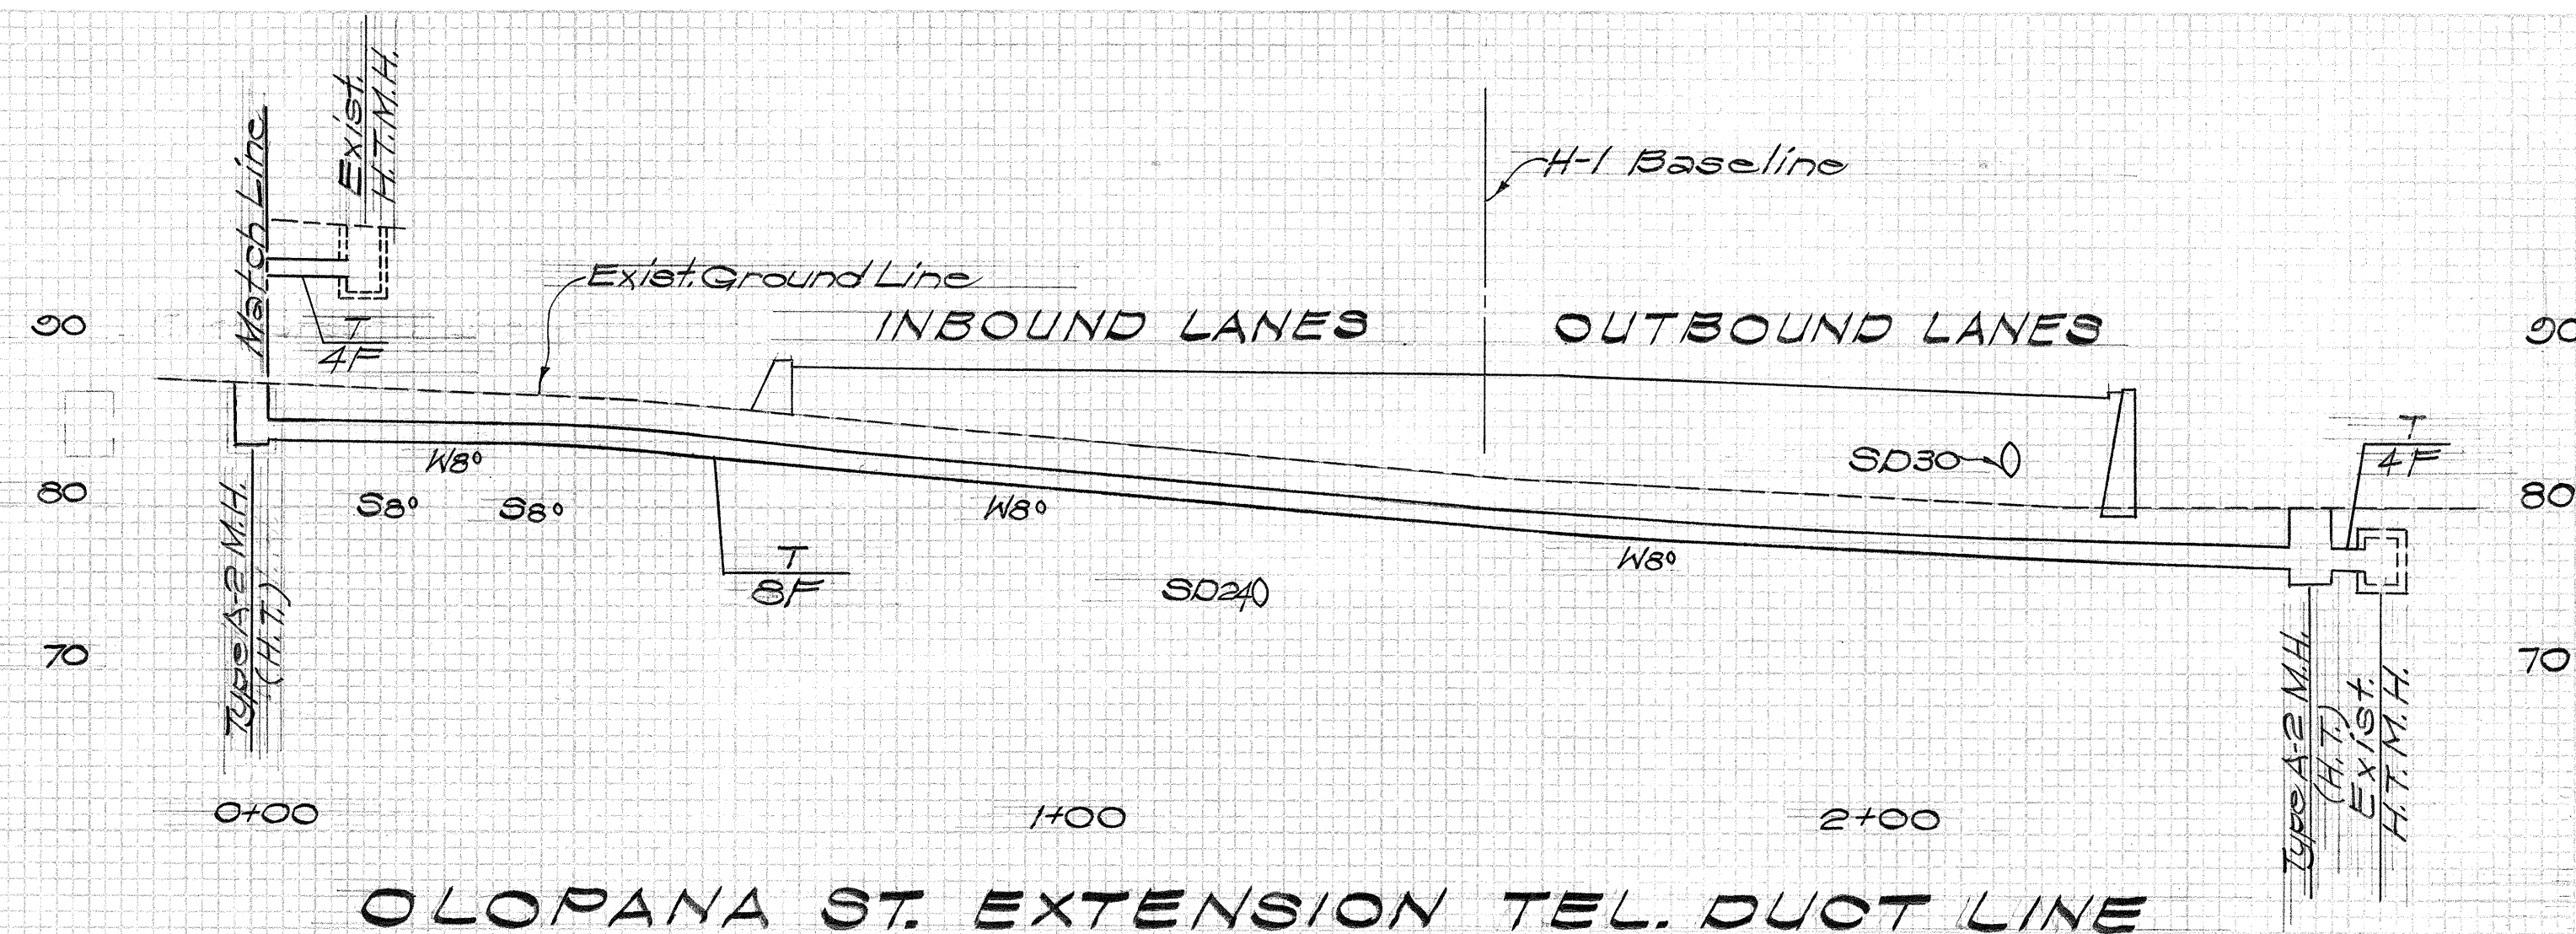


CONDUIT SIZE	SYMBOL
2"	C
3"	D
4"	F
5"	H

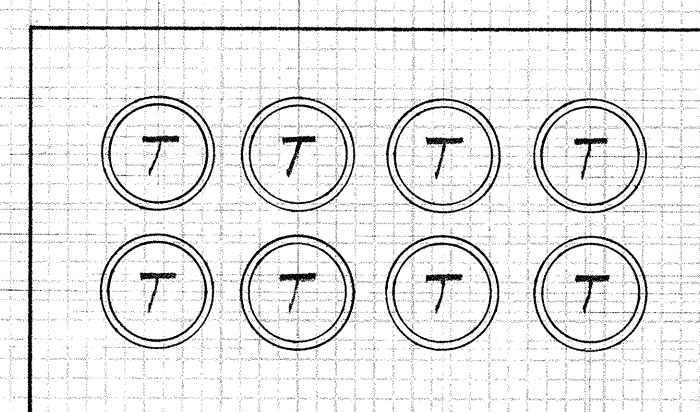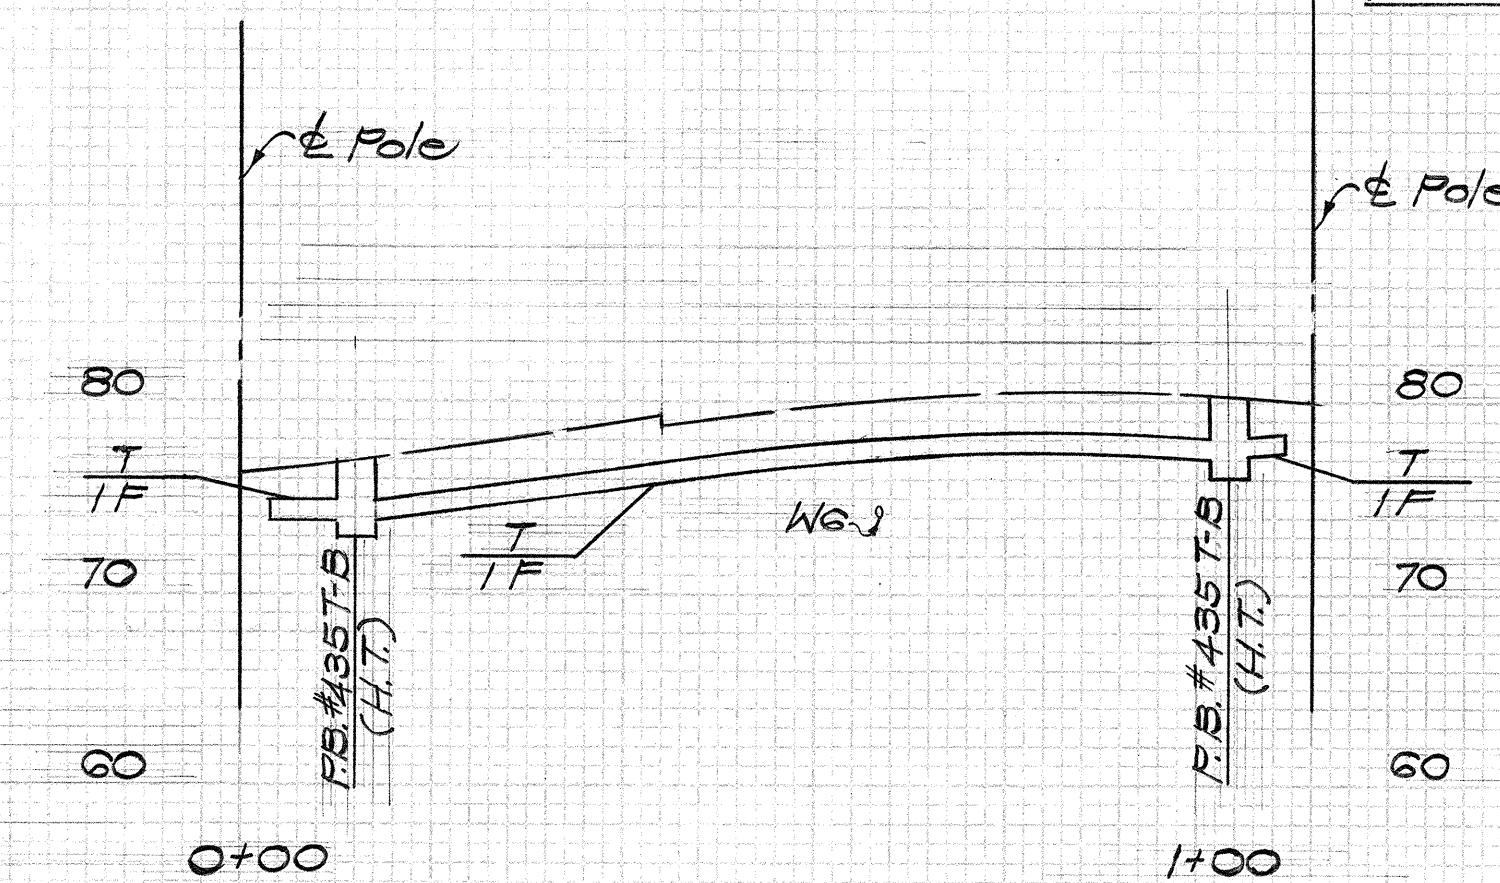


8-4" STYRENE DUCTS (H.T.)

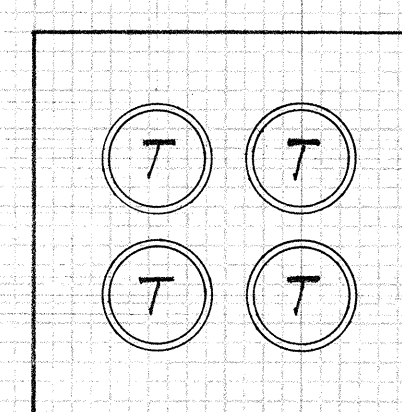


4-4" STYRENE DUCTS (H.T.)

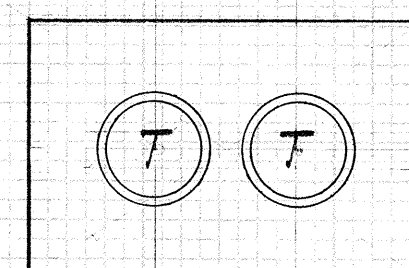


2-4" STYRENE DUCTS (H.T.)

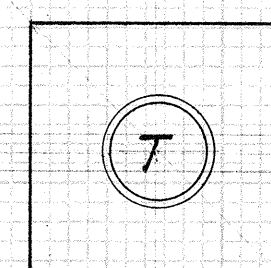

1-4" STYRENE DUCT (H.T.)

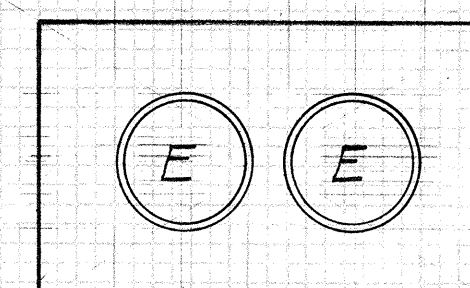


2-5" TRANSITE KORDUCTS (H.E.)

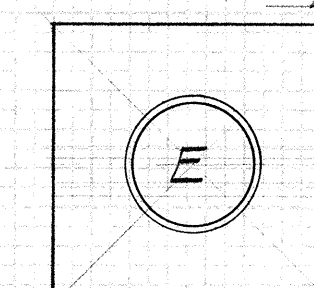


1-5" TRANSITE KORDUCT (H.E.)

AIEA HEIGHTS SEPARATION STRUCTURE

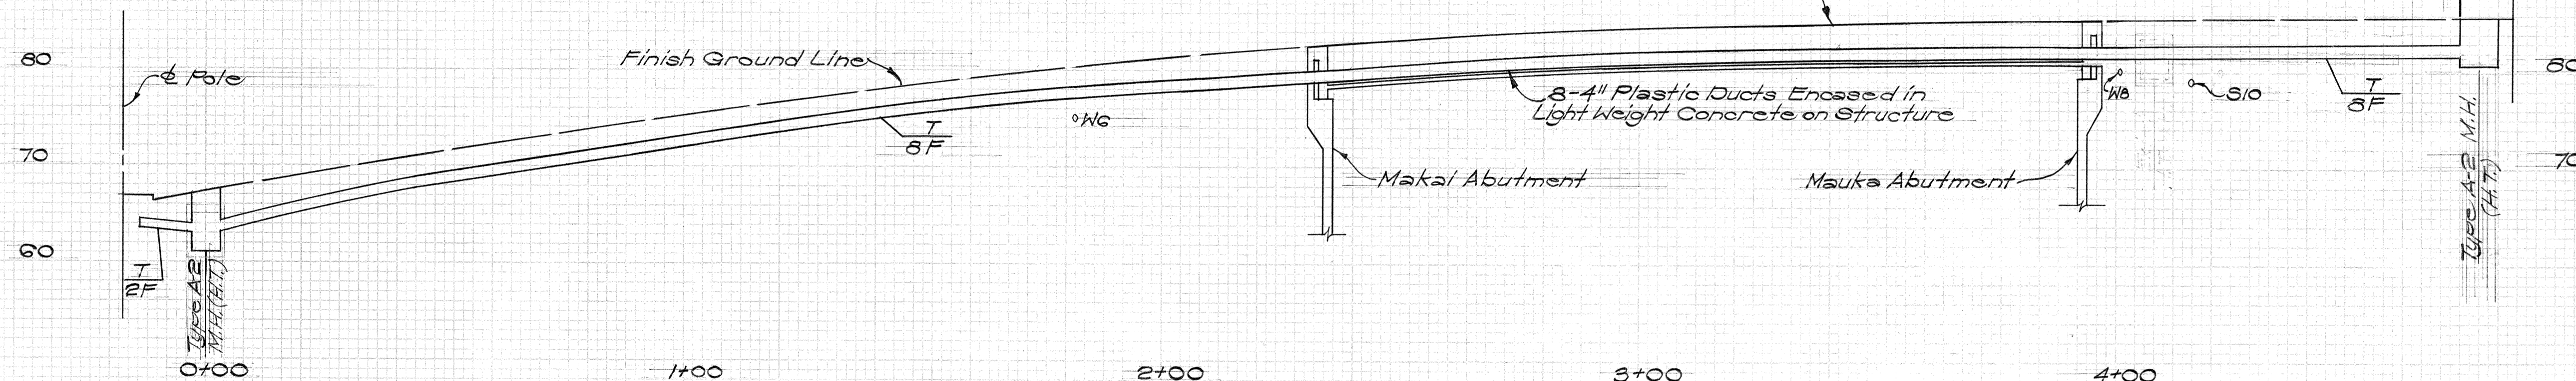

AIEA HEIGHTS DRIVE TELEPHONE DUCT LINE

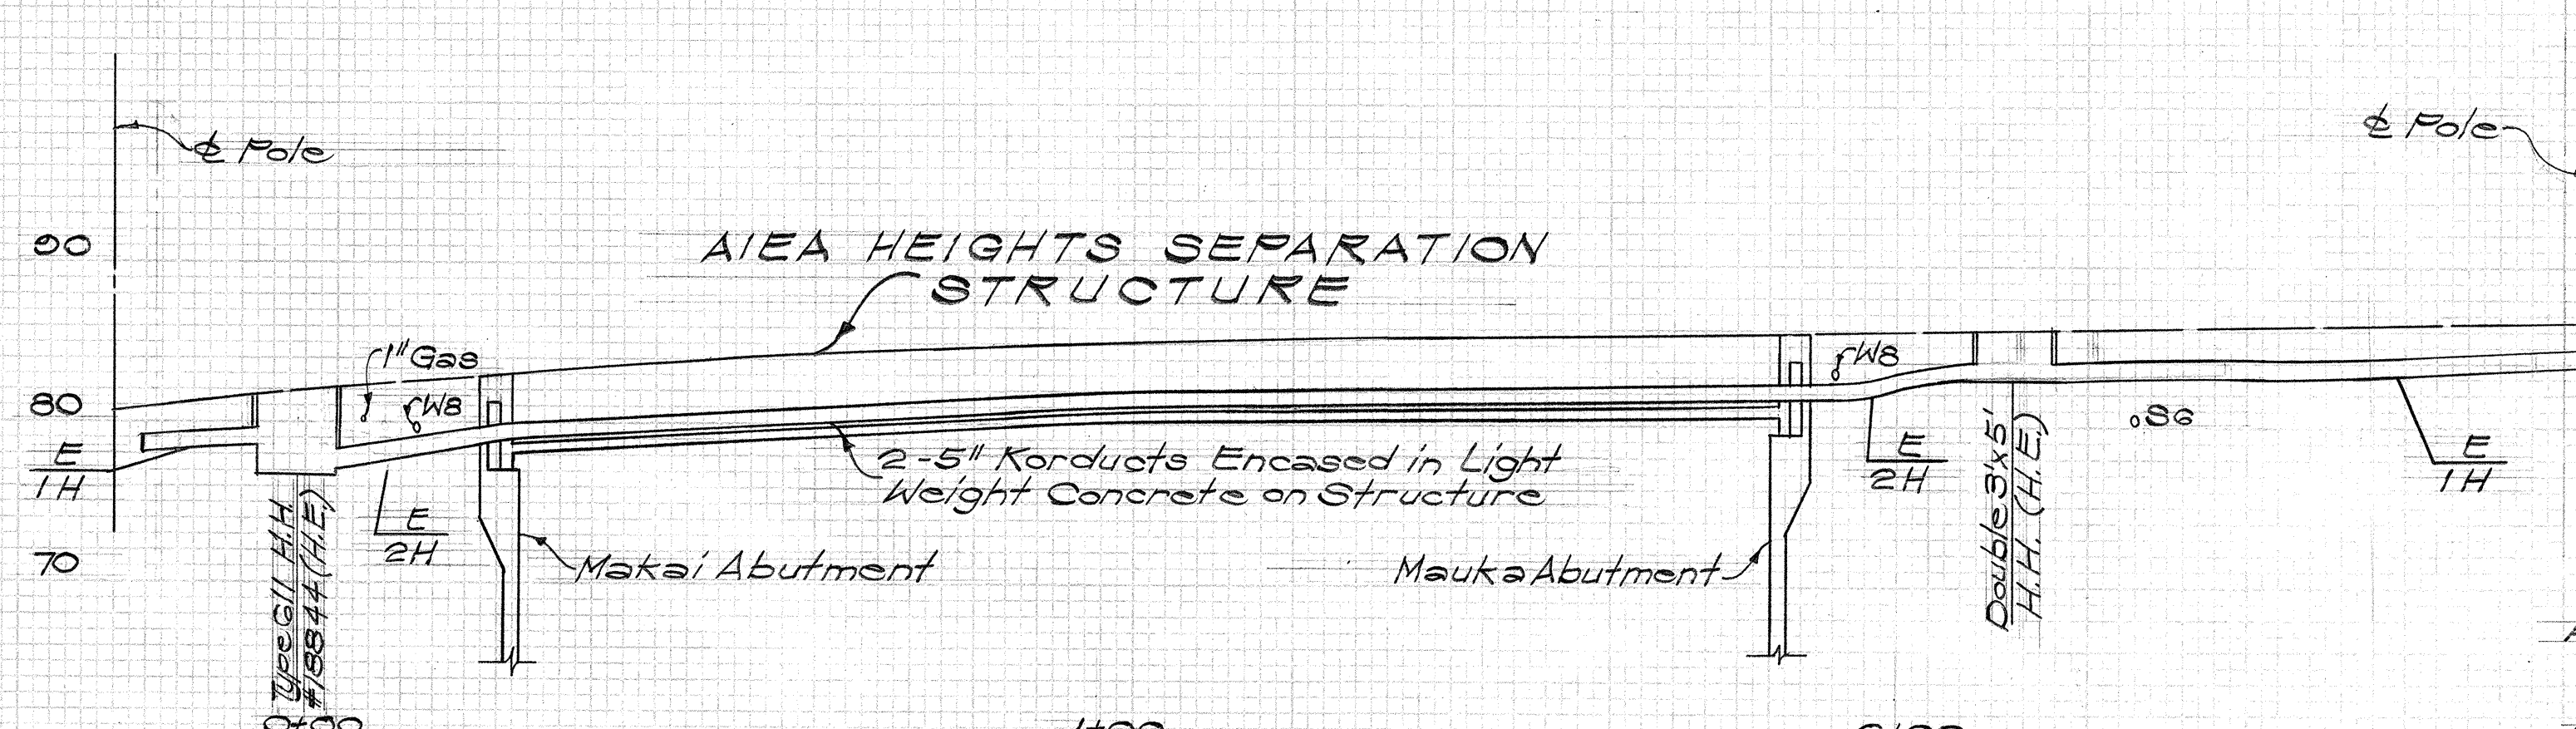

AIEA HEIGHTS DRIVE ELECTRIC DUCT LINE

APPROVED: P. D. Henderson 8-20-68
Hawaiian Electric Company, Inc. Date

APPROVED: F. J. Quill 8-20-68
Hawaiian Telephone Company Date



THIS WORK WAS PREPARED BY ME OR UNDER MY SUPERVISION.

STATE OF HAWAII
DEPARTMENT OF TRANSPORTATION
HIGHWAYS DIVISION

UTILITY PROFILE
ELECTRIC & TELEPHONE





INTERSTATE ROUTE H-1
PROJ. NO. I-HI-1(16):11

Scale: As Shown Date: 8/16/68

SHEET No. 8 OF 27 SHEETS

GENERAL NOTES:

1. Location of side openings in Type "A" Valve Boxes shall correspond to the location of the valve inlet and valve outlet.
2. When the angle control valve is located in the sidewalk area, the valve shall be located at a sufficient depth so as to allow the cover to be replaced with the valve wide open.
3. Do not imprint "Board of Water Supply" and "Water Meter" on the cast iron cover for the Type III Meter Box.
4. All pipes under the pavement shall be copper.
5. Plugs shall be marked with a 1"x2"x1/2" redwood marker. Plug and marker shall be considered incidental to the cost for the various items of the sprinkler system.
6. Pipe sleeves shall have an internal diameter of 1/8" greater than the outside diameter of the pipe passing through the sleeve.
7. Final location of meter boxes and valves shall be determined by the Engineer.
8. Pipes shall be galvanized steel and fittings shall be malleable iron unless otherwise called for.
9. When the consumers water service will be interrupted, the Contractor shall notify each consumer and the Board of Water Supply concerning the time and duration of the shut-down.
10. Asterisk(*) indicates work will be performed by the Board of Water Supply. Materials shall be furnished by the Contractor.
11. See Sht. 49 for general water notes.

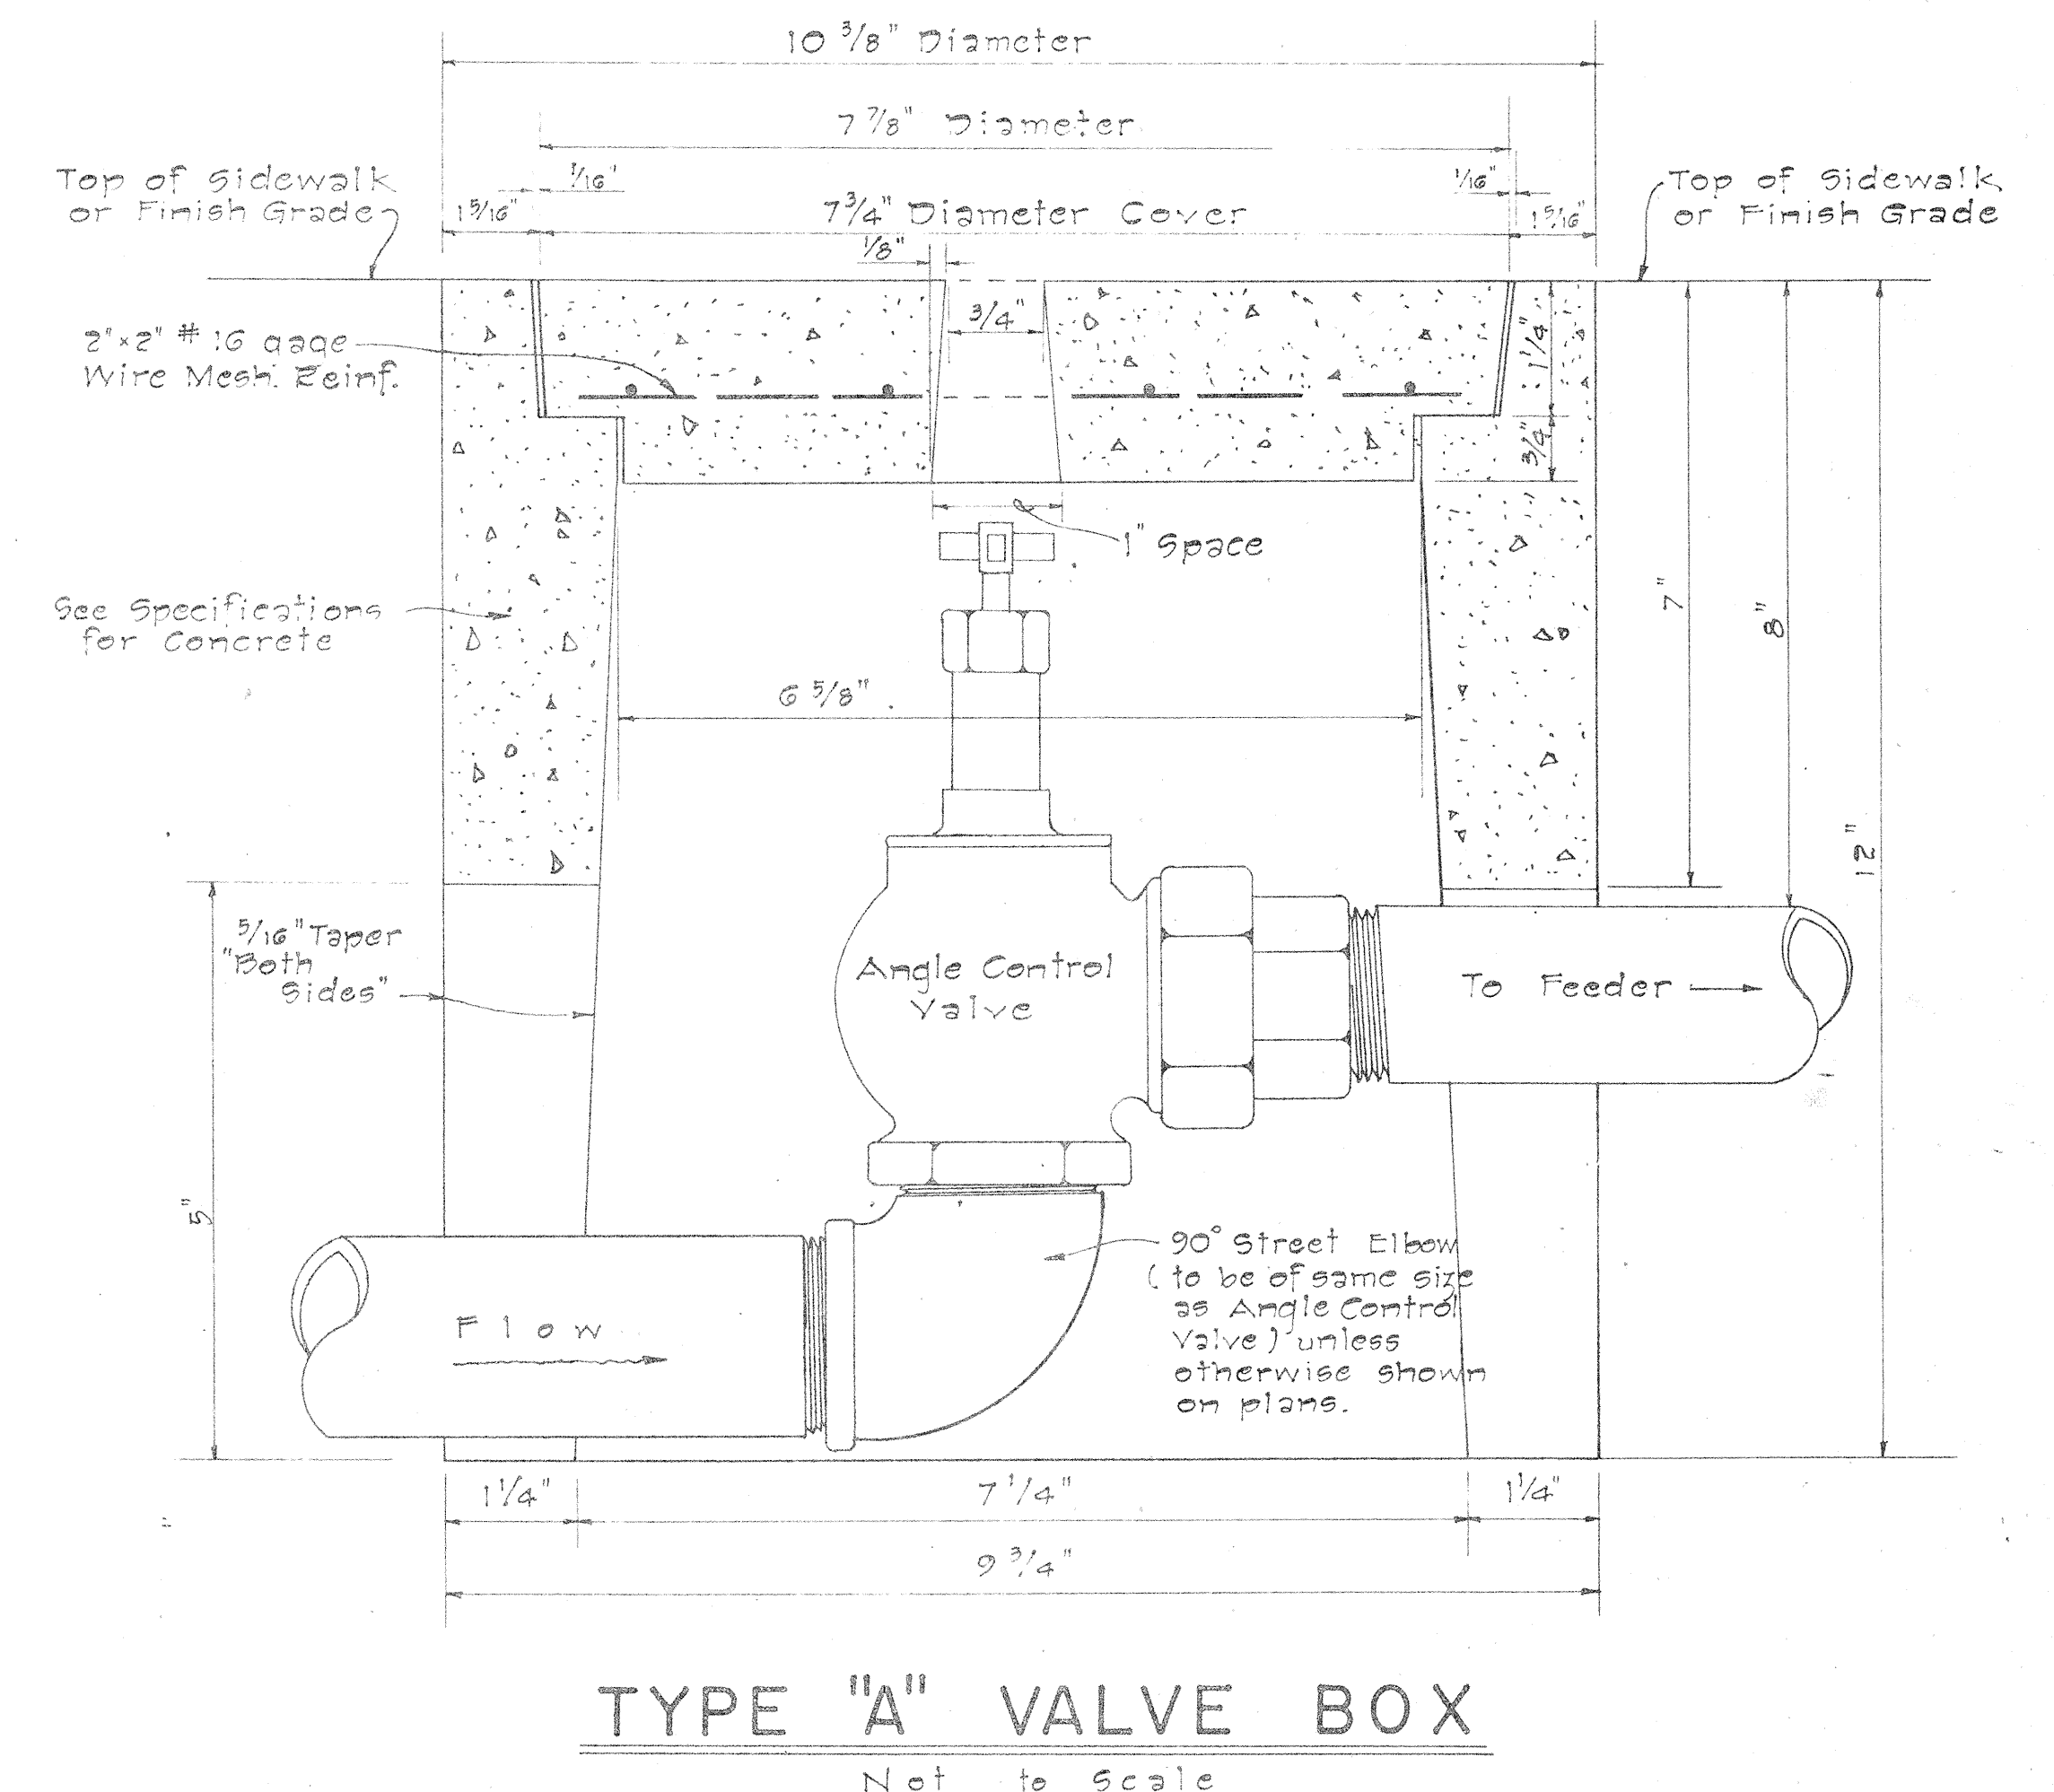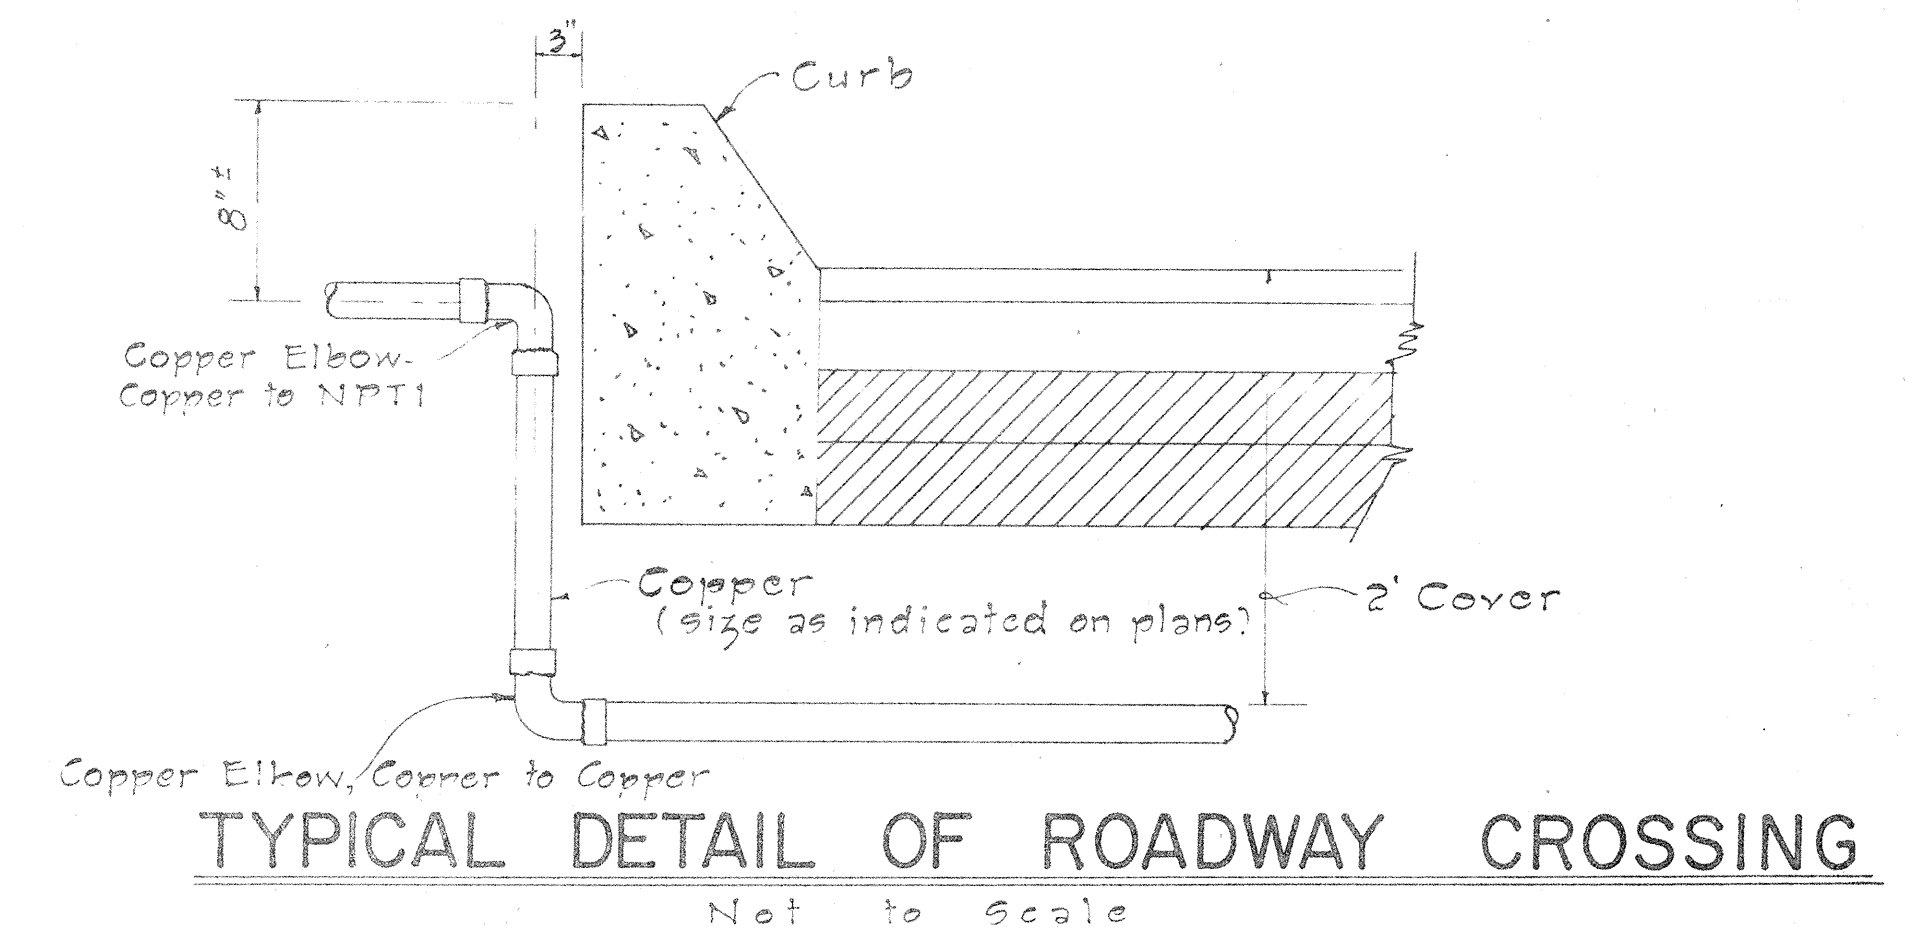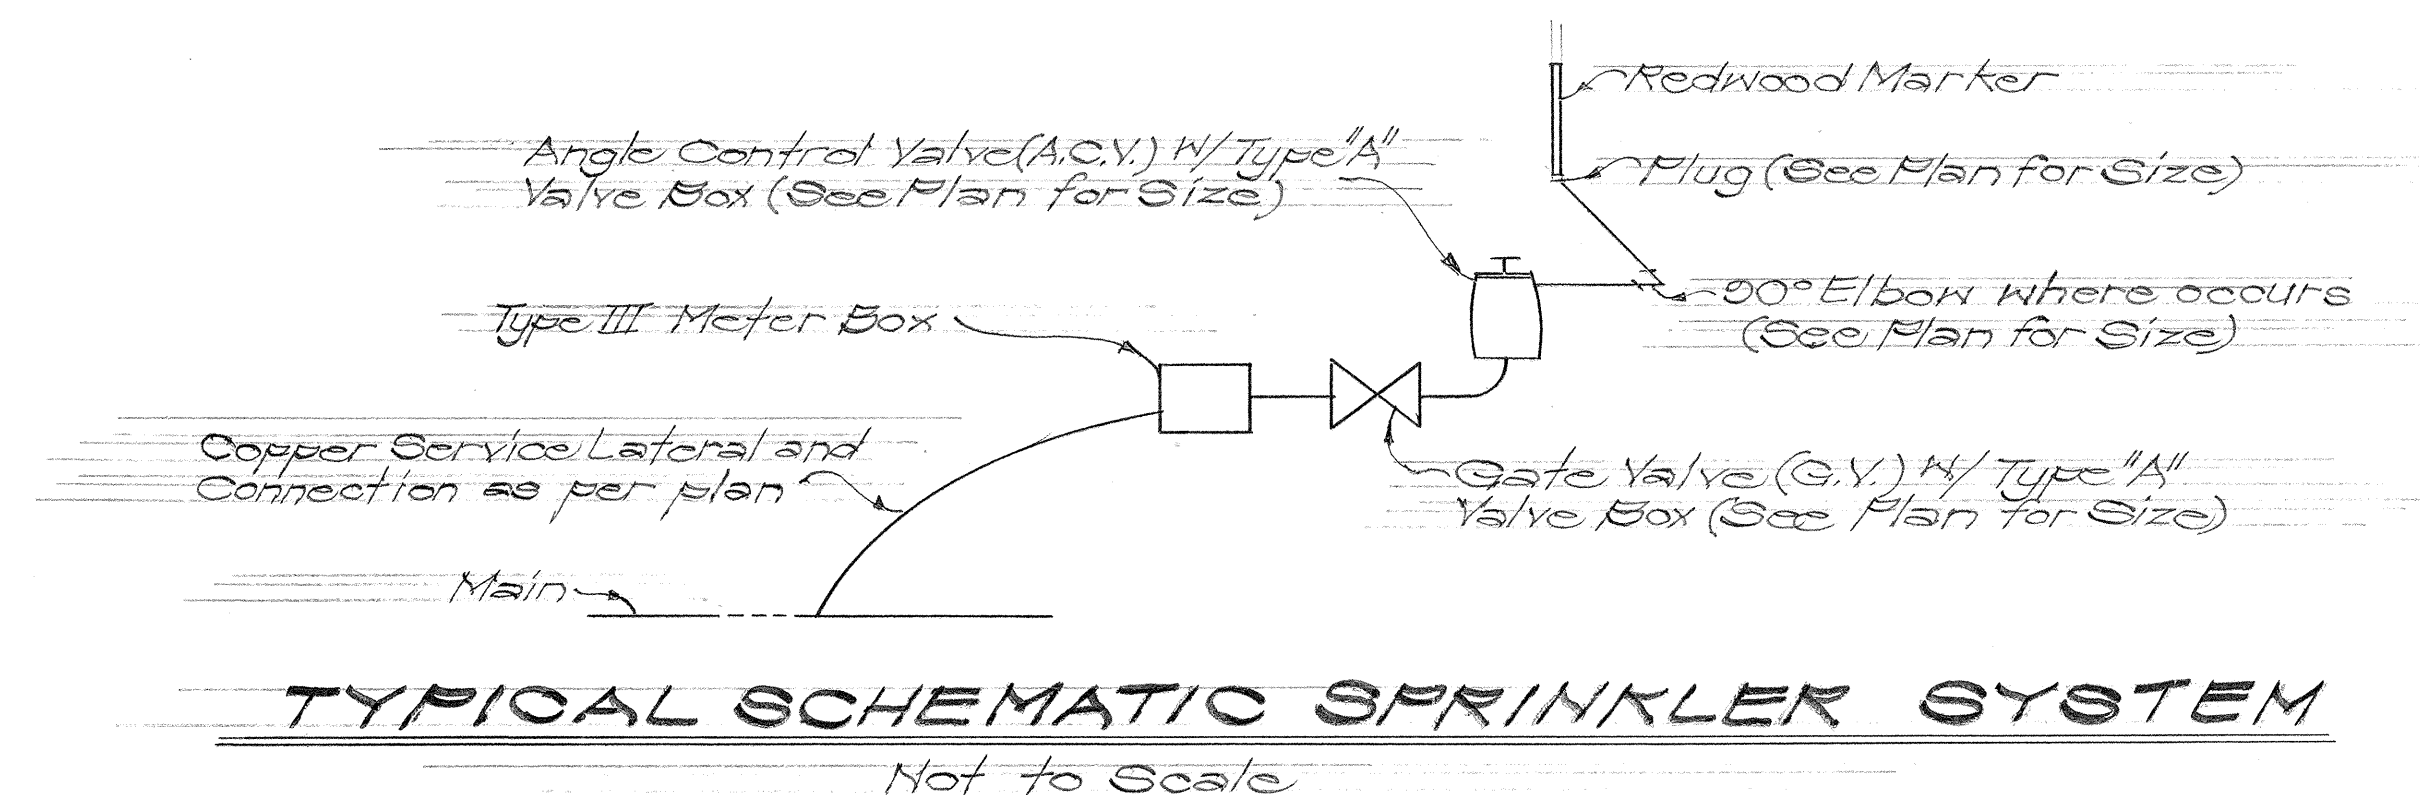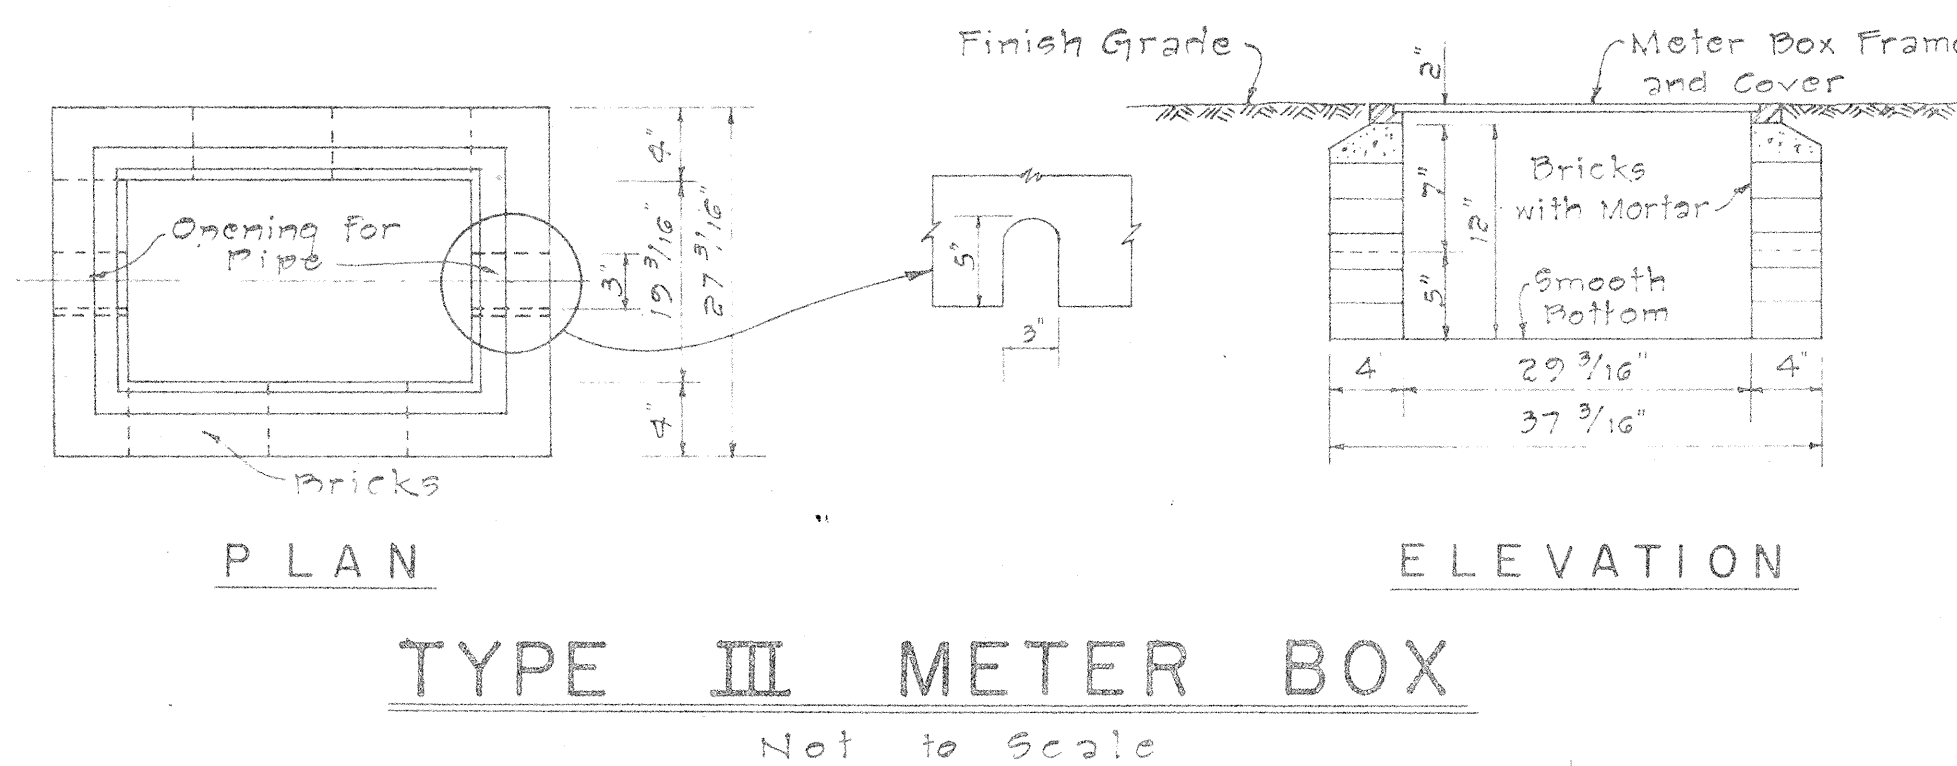

THIS WORK WAS PREPARED BY
ME OR UNDER MY SUPERVISION.

STATE OF HAWAII
DEPARTMENT OF TRANSPORTATION
HIGHWAYS DIVISION

MISCELLANEOUS
SPRINKLER DETAILS

INTERSTATE ROUTE H-1
PROJ. No. I-H-1 (16)11

Scale: As Shown Date: 8/10/68


SHEET No. 2 OF 27 SHEETS

FED. ROAD DIST. NO.	STATE	FED. AID PROJ. NO.	FISCAL YEAR	SHEET NO.	TOTAL SHEETS
HAWAII	HAWAII	I-HI-1(64)12, UNIT 2	1969	58	128
		I-HI-1(67)11			



SCHEDULE OF COPPER FITTINGS (SOLDERED JOINT)

ITEM NO.	DESCRIPTION	SINGLE SERVICE CONN.			MULTIPLE SERV. CONN.	
			TWO SERVICES	THREE SERVICES		
1	Corporation Stop Brass (H-10003)	1	1	1		
2	Ground Joint Union (Style Copper To N.P.T.E. No. C-109)	1	1	1		
3	Adapter, Copper To N.P.T.E. (Style No. C-101)	2	1	1		
4	Stopcock Brass (B.W.S. Standard)	1	1	1		
5	Fitting Adapter, (Style Fitting To N.P.T.E. No. C-104)	—	1	1		
6	Tee, Copper To Copper To Copper (Style No. T-300)	—	1	1		
7	Bushings, Fitting To Copper (Style No. C-103)	—	2	2		
8	90° Elbow, Copper To Copper (Style No. C-200)	—	2	2		
9	Adapter, Copper To N.P.T.E. (Style No. C-101)	1	2	3		
10	Stopcock Brass (B.W.S. Standard)	1	2	3		
11	Reducing Tee, Copper To Copper To Copper (Substitute For Items Number 6 and 7). (Style No. T-300)	—	1	1		
12	Tee, Copper To Copper To Copper (Style No. T-300)	—	—	1		
13	Bushing, Fitting To Copper (Style No. C-103)	—	—	1		
14	Reducing Tee, Copper To Copper To Copper (Substitute For Items Number 12 and 13 (Style No. T-300)	—	—	1		

NOTE:
Reference Numbers shown thus (H-10003) are from Mueller Co. Catalog "H" and (Style No. T-300) are from Mueller Brass Co. "Streamline" Catalog S-354. Approved Equal may be used.


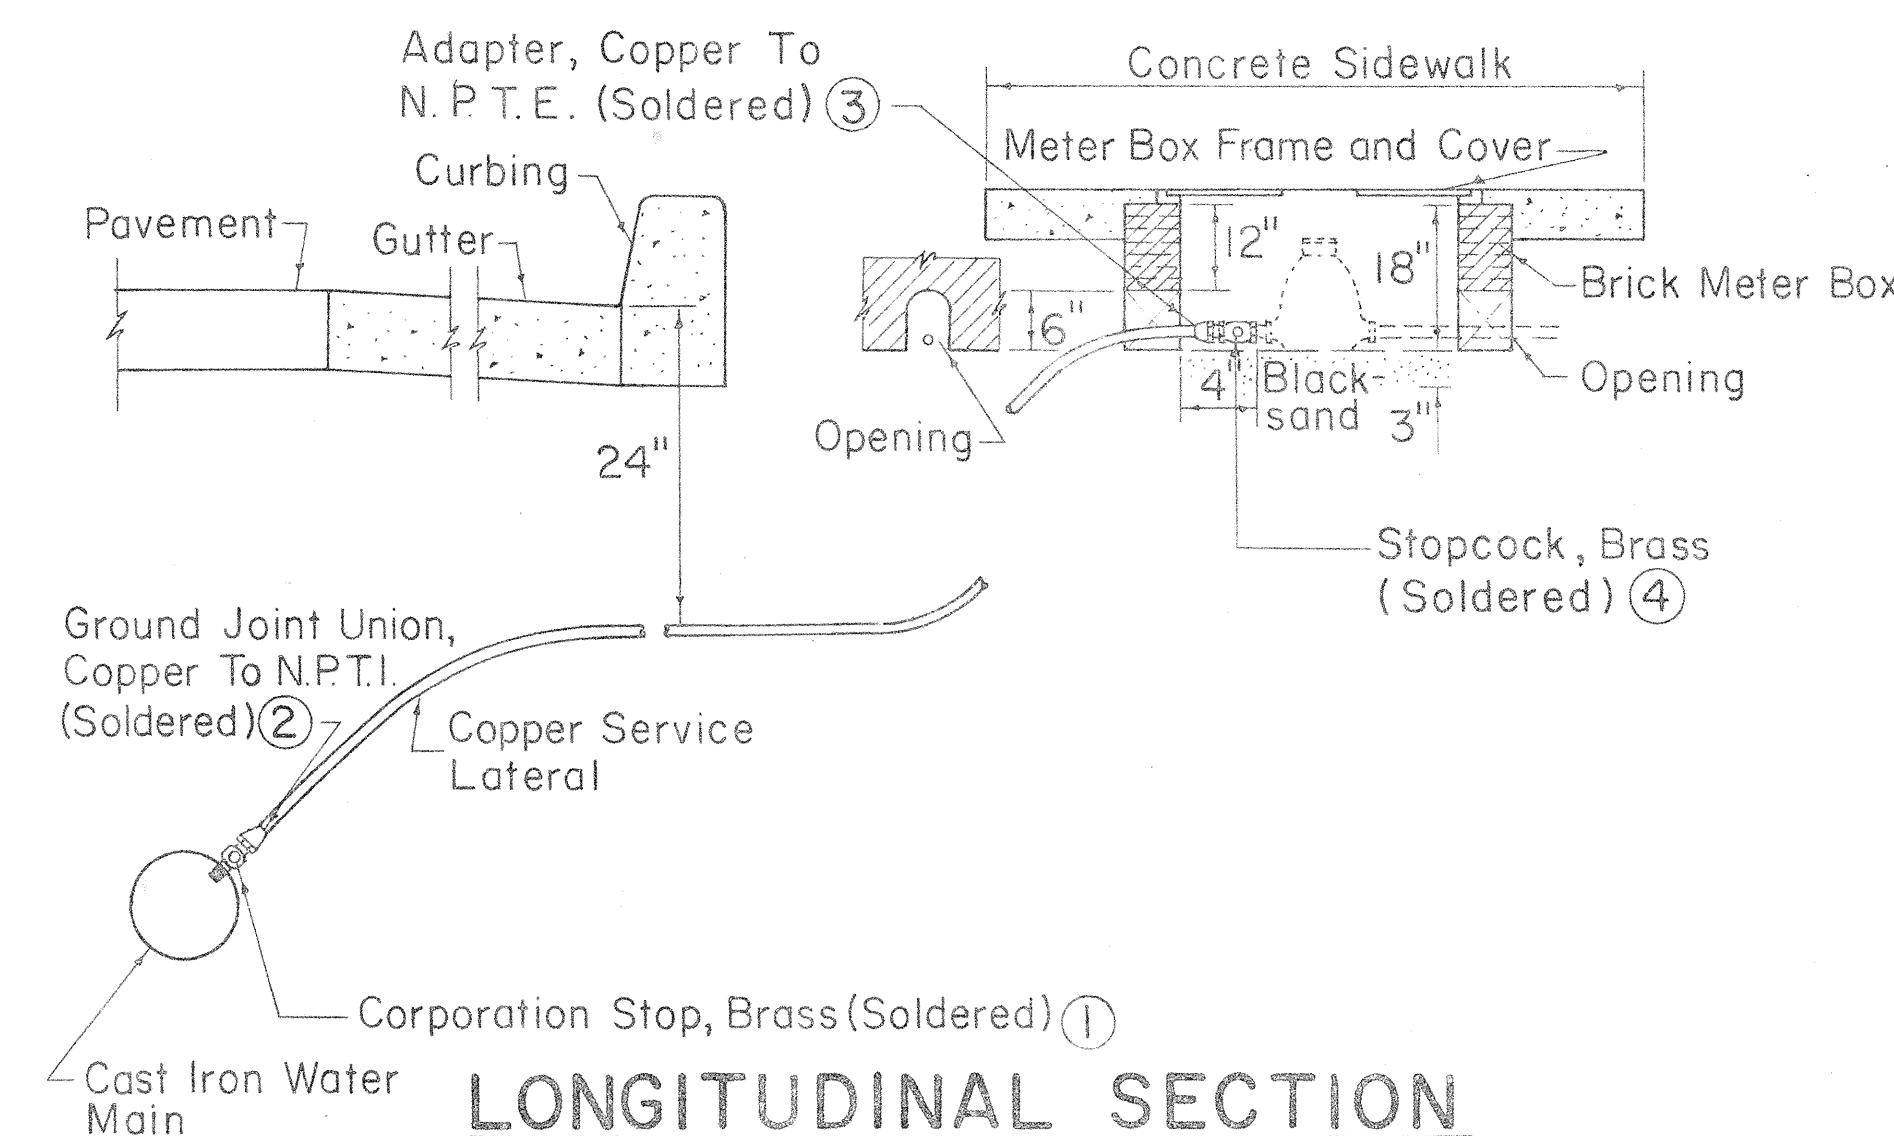


NOTE:
All castings shall be made accurately to the dimensions shown. Seat and cover shall be machined or ground where necessary to secure flat and true surfaces. The cover shall not rattle in any position.

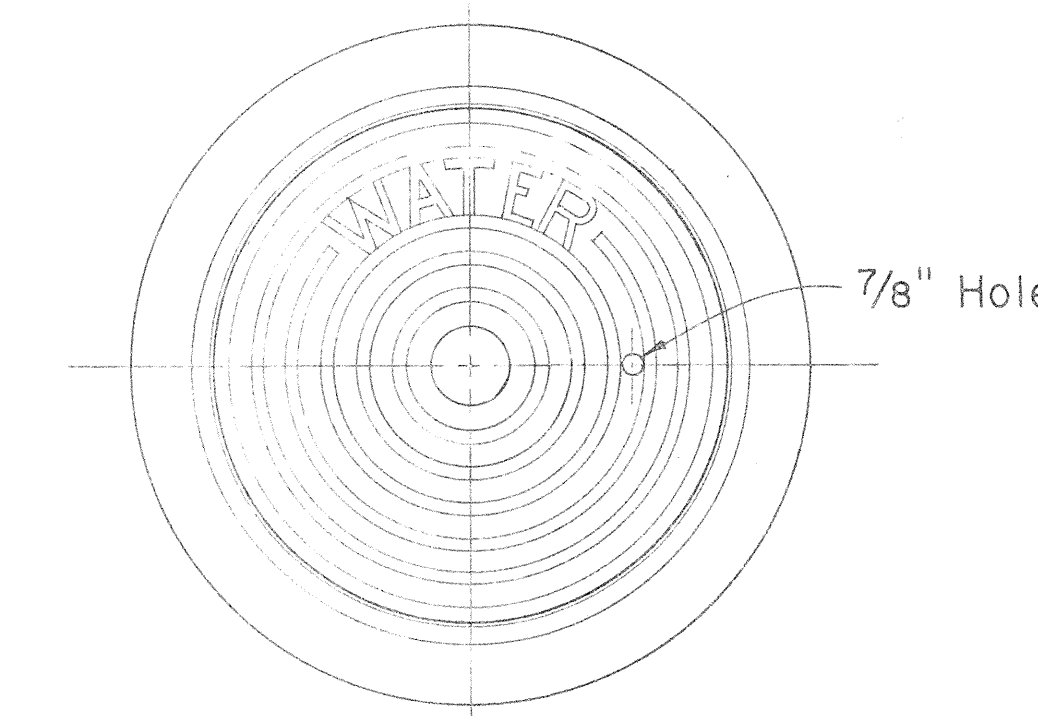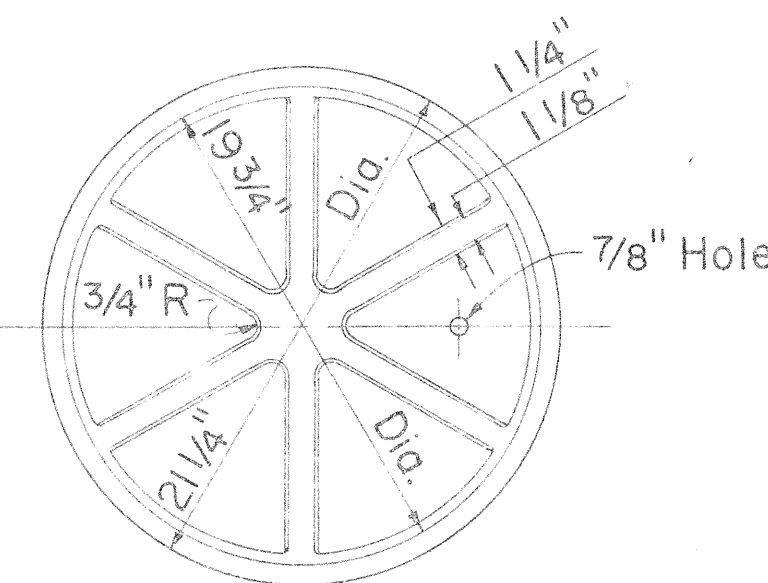


MANHOLE FRAME & COVER CAST IRON, 20" SIZE

SCALE: 1-1/2" = 1'-0"

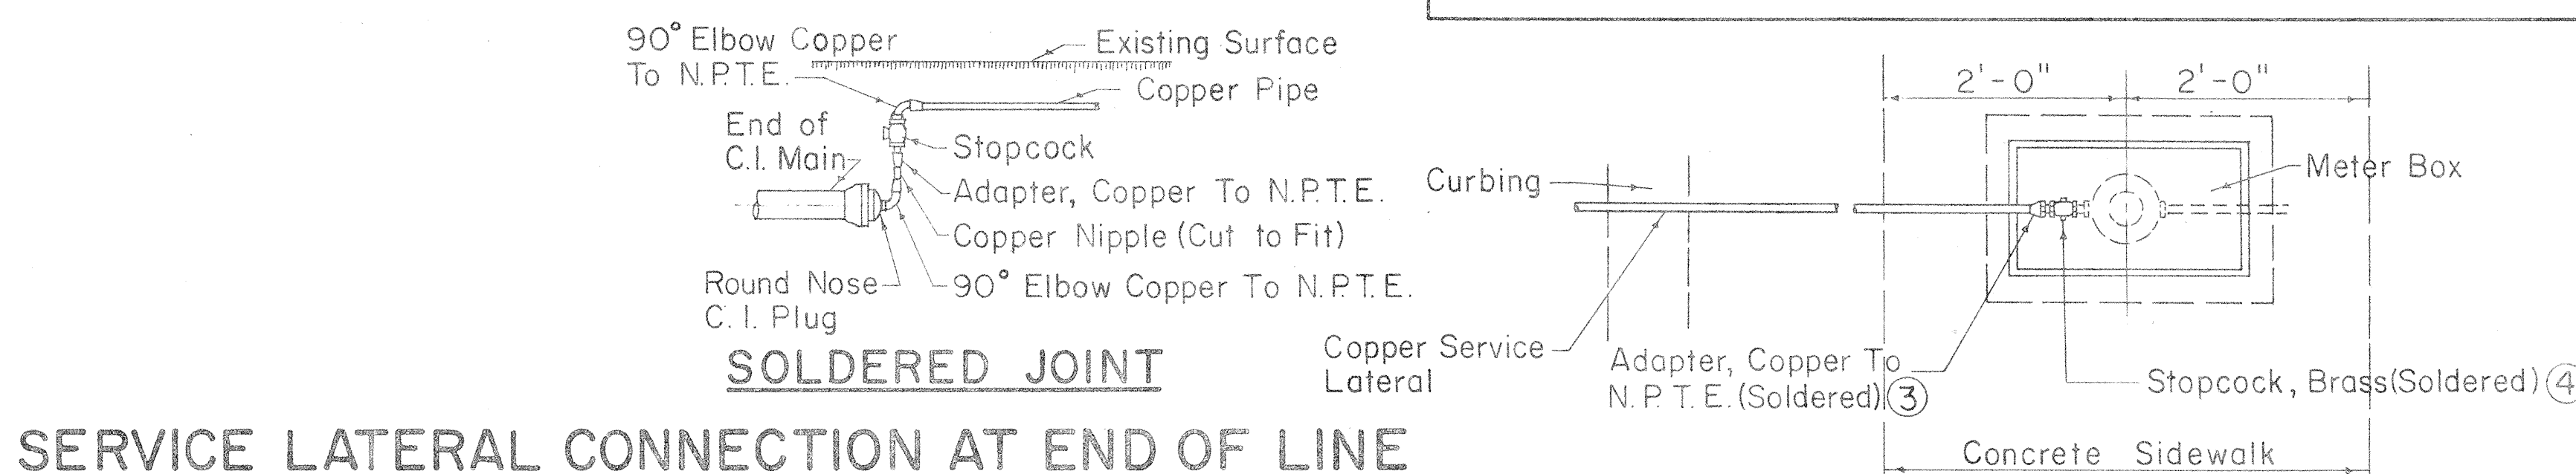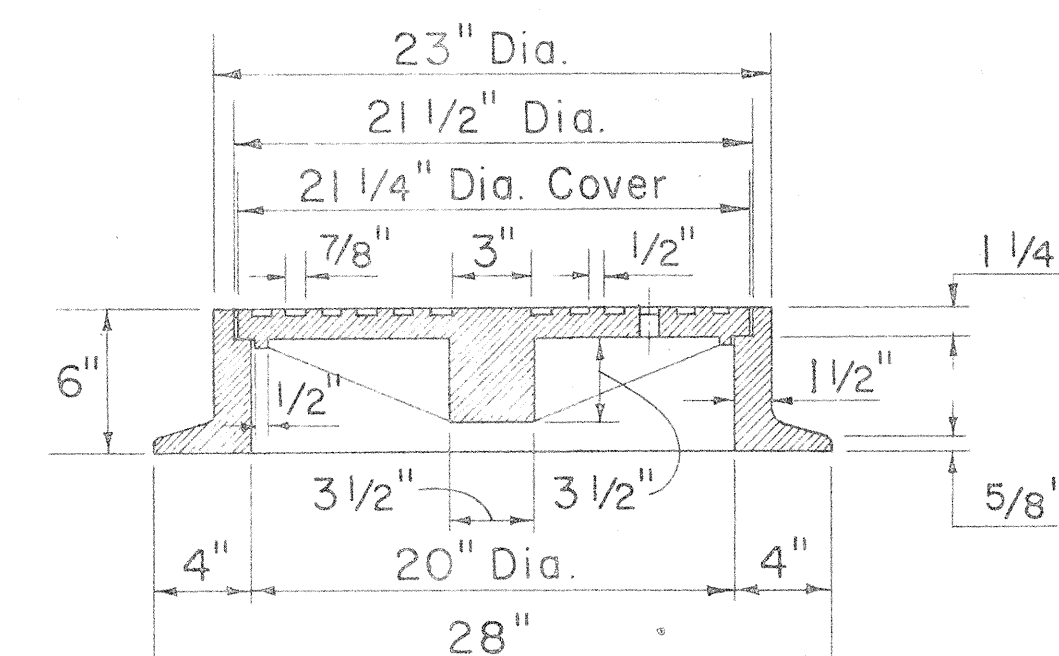


SERVICE LATERAL CONNECTION AT END OF LINE

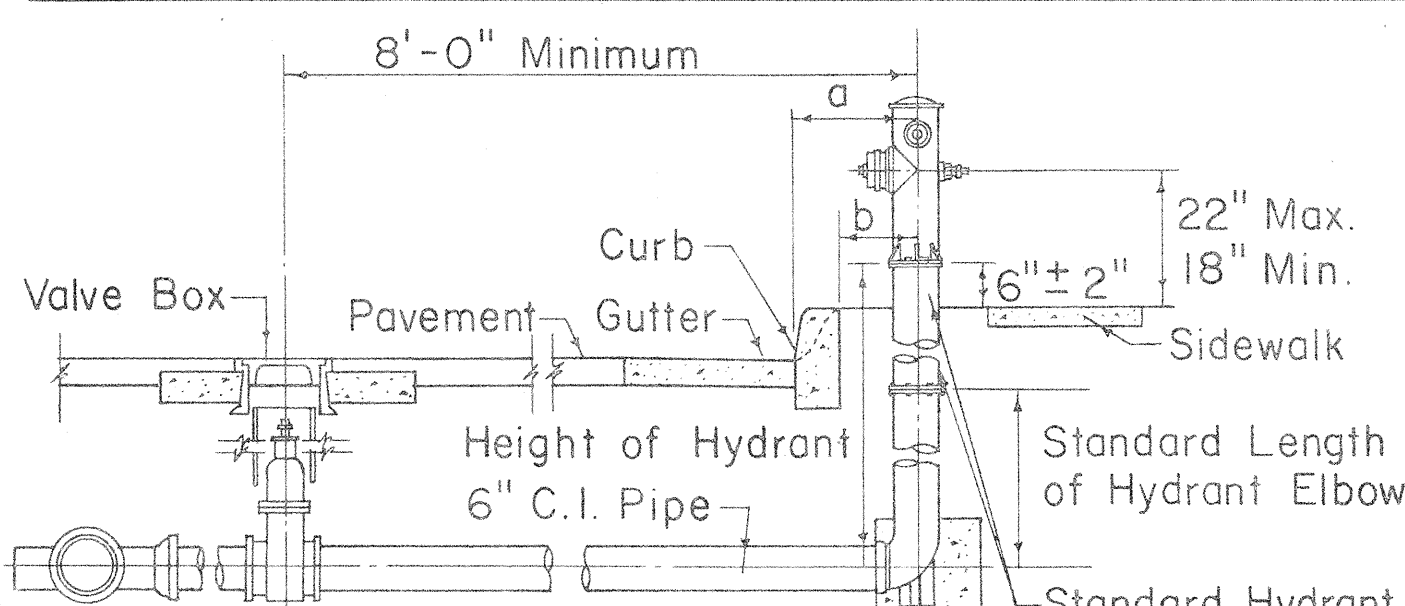

a	20" Min. (Standard Curb)
b	20" Min. (Roll Curb)


NOTE:
Gaskets for flanged joints shall be 1/6 inch duck-inserted rubber packing Garlock No. 19. Bolts shall be 5/8 inch diameter x 2 3/4 inch long steel machine bolts with cut threads, American Standard heavy hexagon heads, galvanized. Nuts shall be American Standard heavy cold punched hexagon nuts, galvanized.

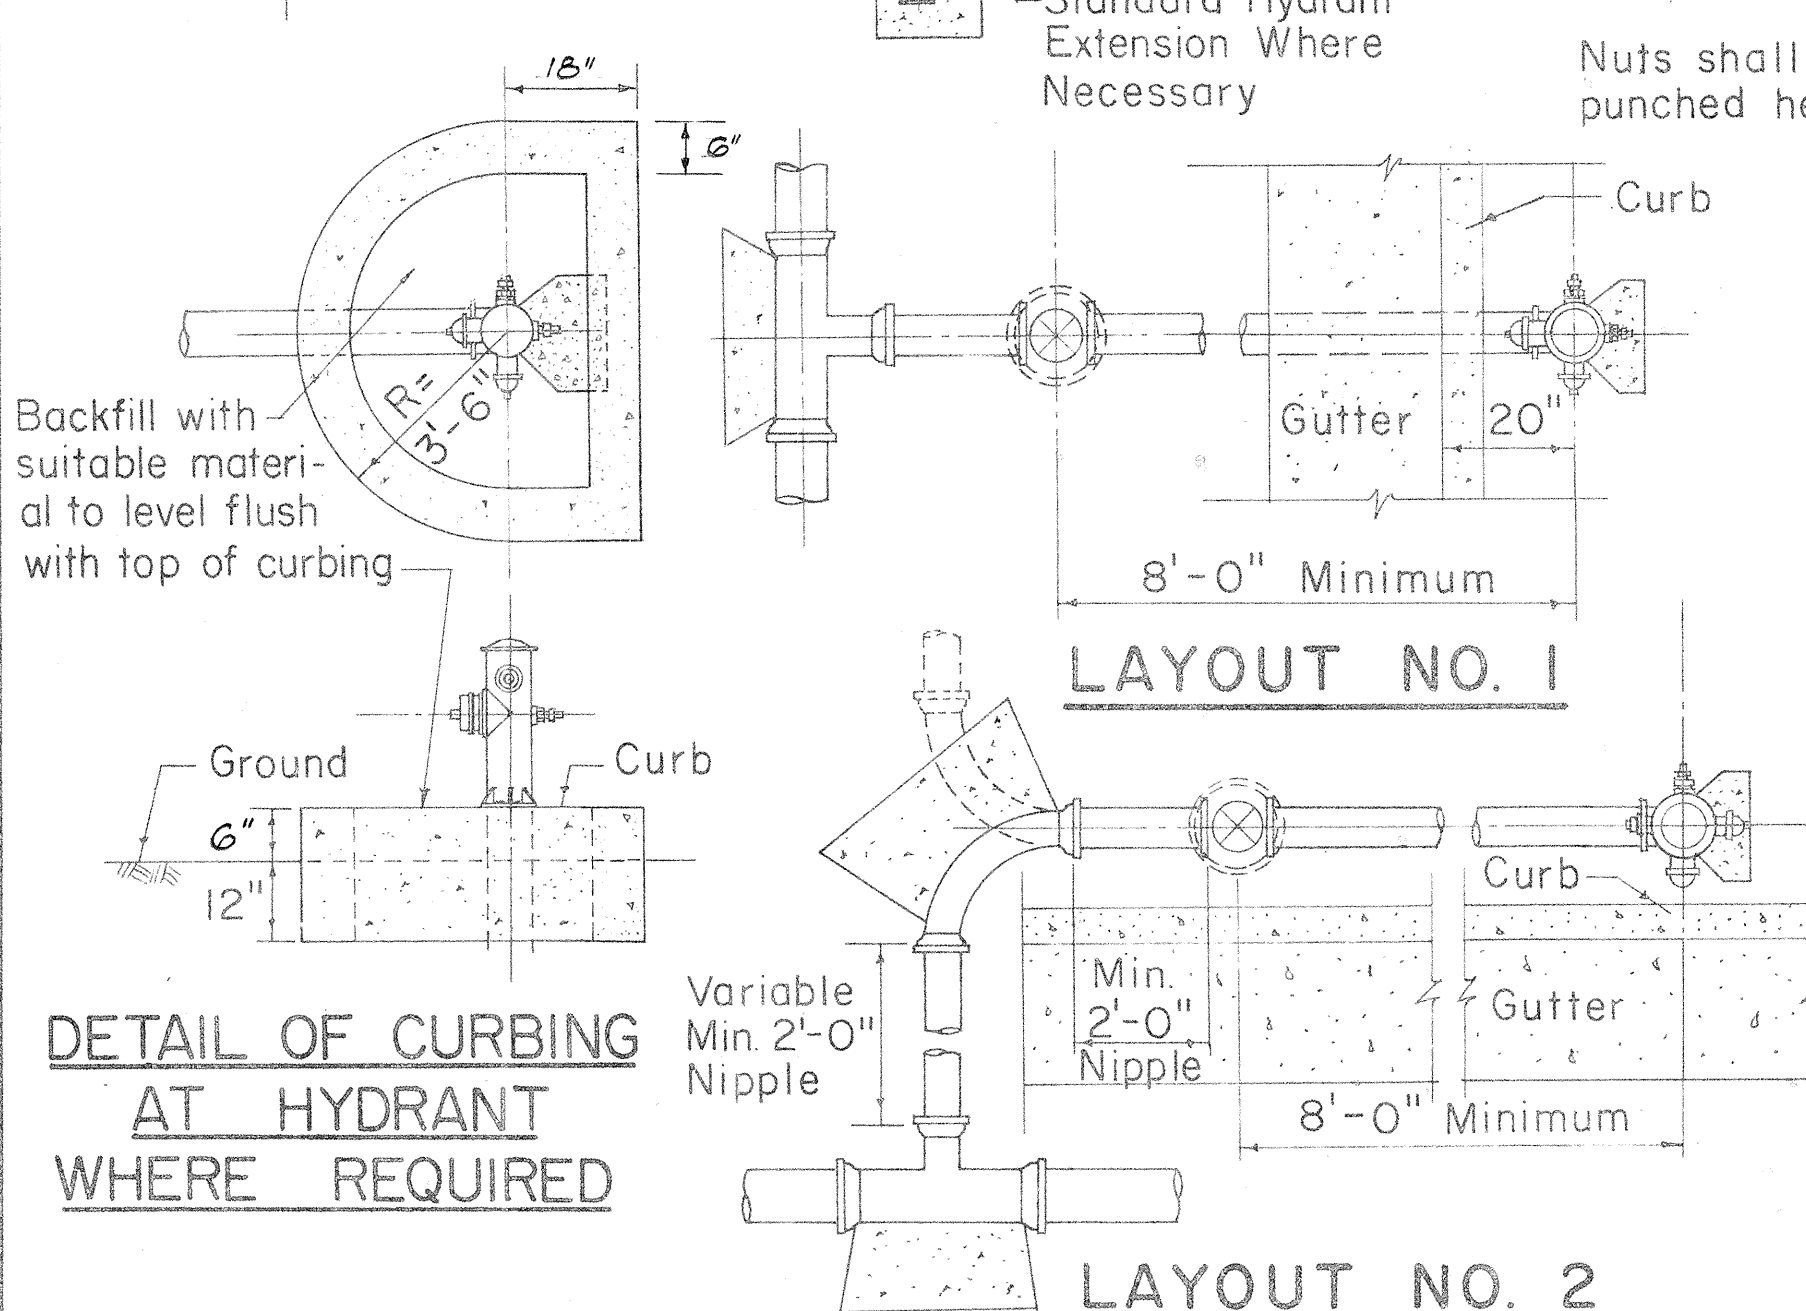

STANDARD FIRE HYDRANT LAYOUT

STANDARD LENGTHS FOR HYDRANT ELBOWS
30"
36"
42"
48"

Standard Hydrant Extensions are available in the following Lengths:
6 to 30 inches long in increments of 6 inches

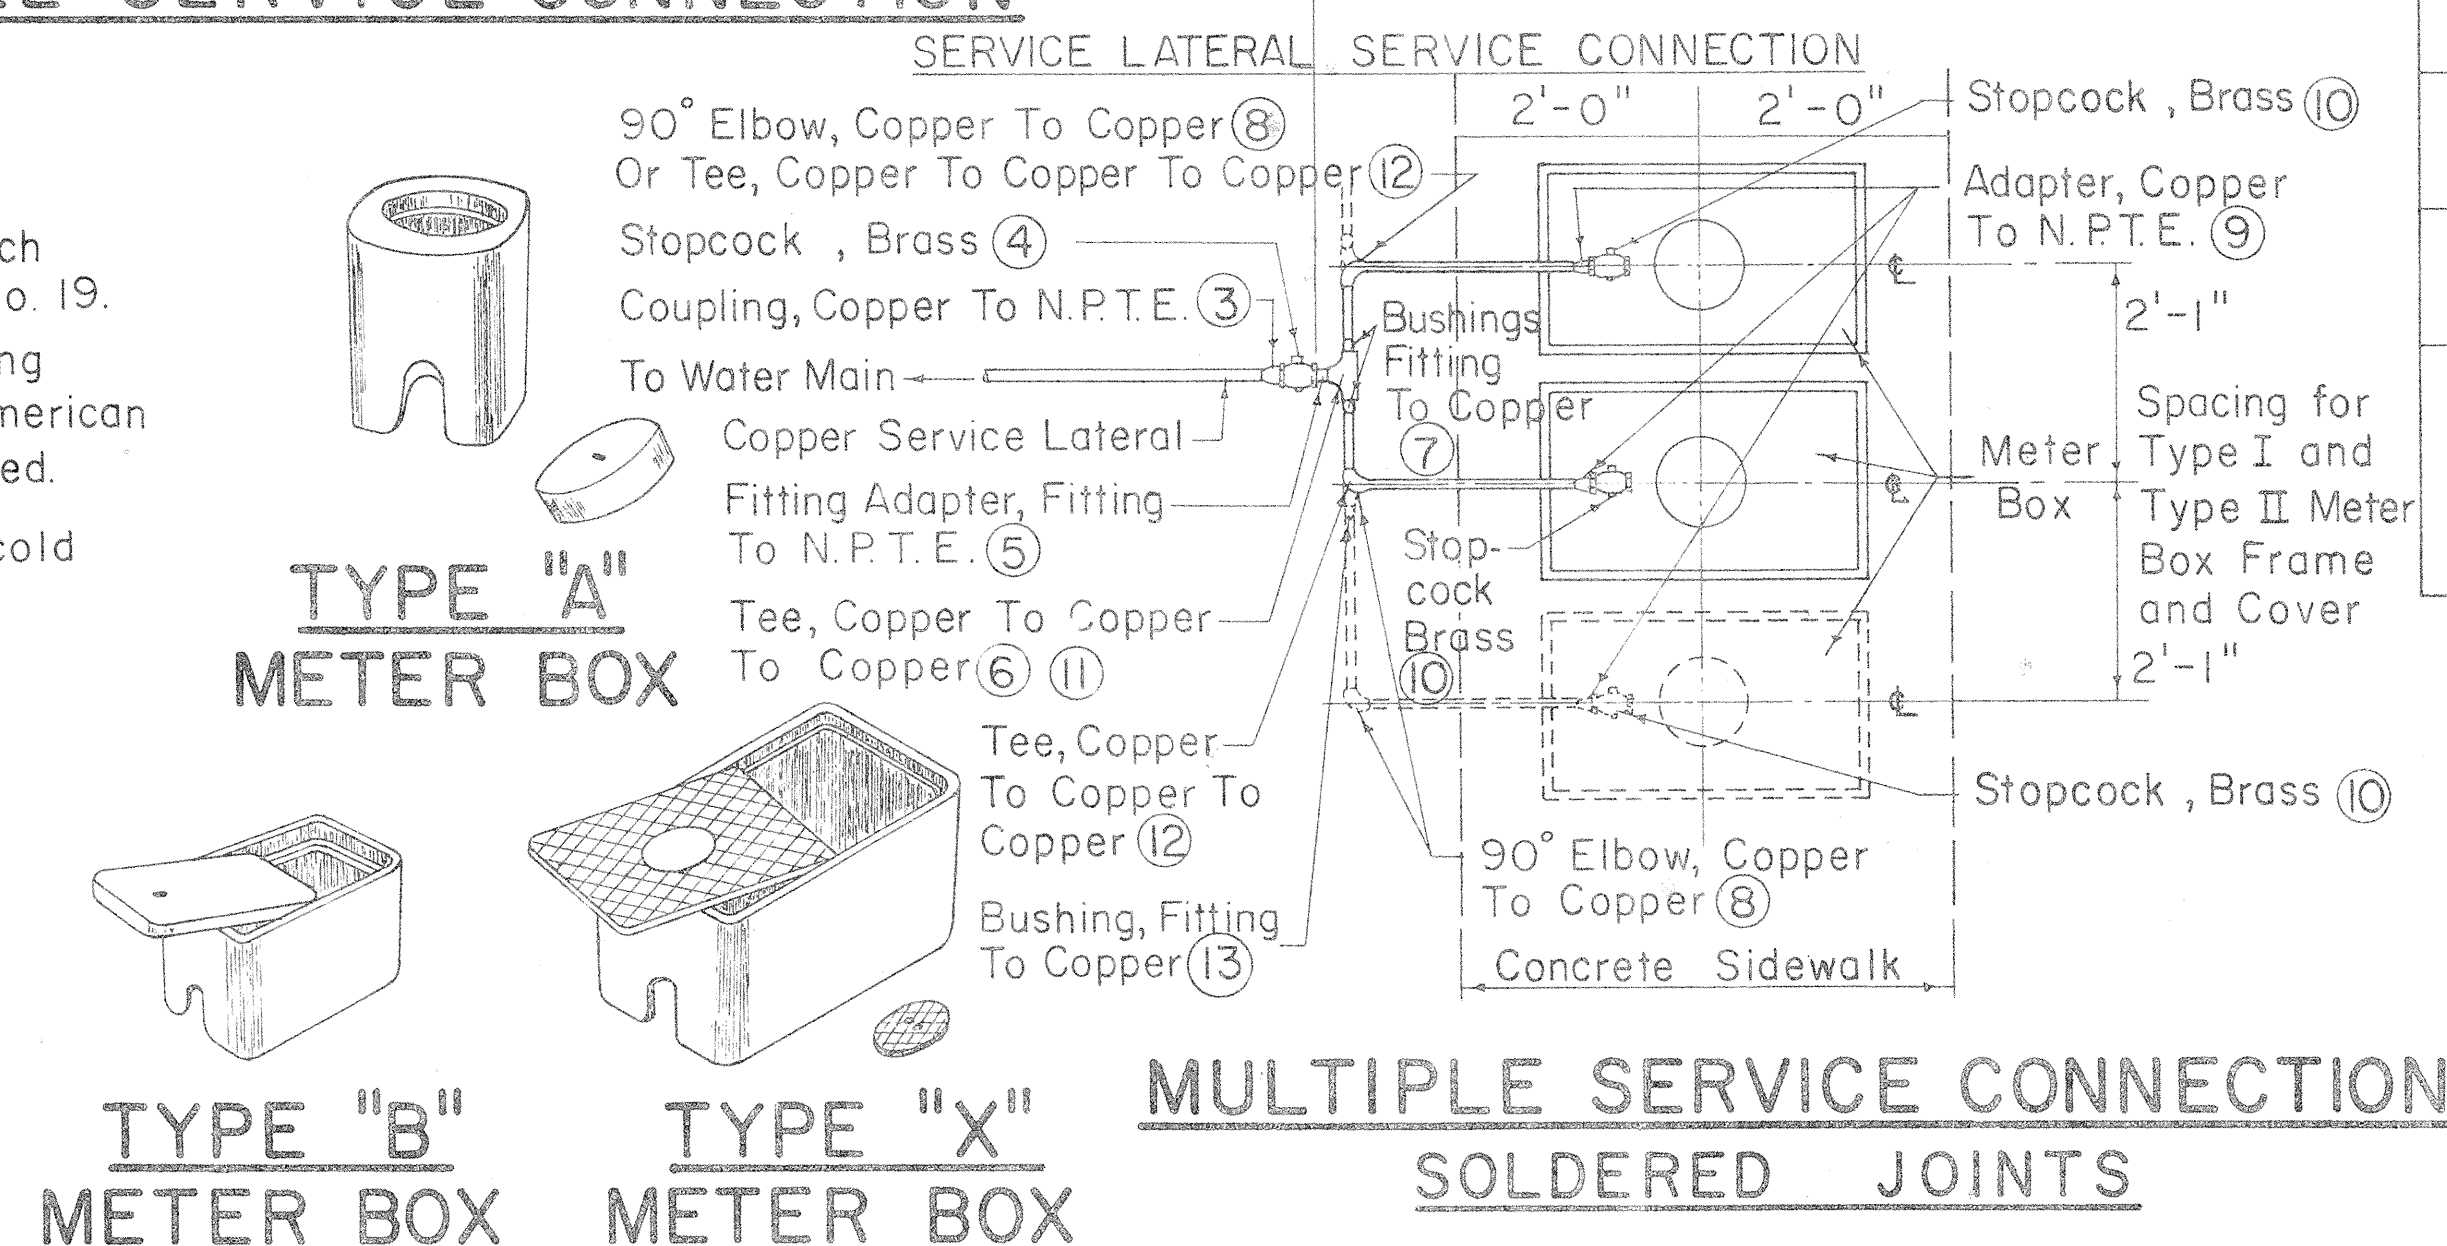

METER BOX DATA					
TYPE METER BOX	METER SIZES	OVERALL DIMENSIONS AT BOTTOM	OVERALL DIMENSIONS AT TOP	COMPLETE WEIGHT	OVERALL DIMENSIONS OF LID
A	5/8" or 3/4" Without Valve	7 1/4" x 7 1/4"	10" x 10"	45 lbs.	7 3/8" Dia.
B	5/8" or 3/4"	9 1/2" x 16"	12 1/4" x 18 3/8"	82 lbs.	8 3/4" x 14 1/2"
X		14 1/2" x 23 1/2"	16" x 25"	143 lbs.	13 1/8" x 22 1/8"


APPROVED:
A. H. Kamae
CHIEF, ENGINEERING DIVISION
BOARD OF WATER SUPPLY
DATE 8/1/68

STATE OF HAWAII
DEPARTMENT OF TRANSPORTATION
HIGHWAYS DIVISION
BOARD OF WATER SUPPLY
CITY & COUNTY OF HONOLULU
STANDARD WATER DETAILS
INTERSTATE ROUTE H-1
PROJ. NO. I-HI-1 (16) 11
Scale: As Noted
Date 8/16/68


SHEET NO. 10 OF 27 SHEETS

FED. ROAD DIST. NO.	STATE	FED. AID PROJ. NO.	FISCAL YEAR	SHEET NO.	TOTAL SHEETS
HAWAII	HAWAII	I-HI(64)12, UNIT 2	1969	59	128
		I-HI(66)11			


NOTE:
Contractor to furnish 1/2" brass plug (Tapered thread) to replace corporation stop upon completion of chlorination.

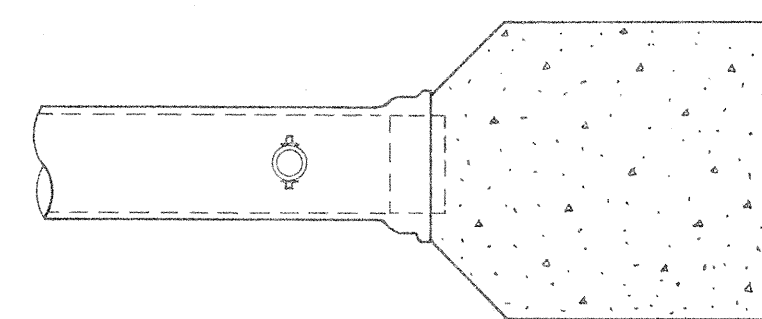

TOP VIEW


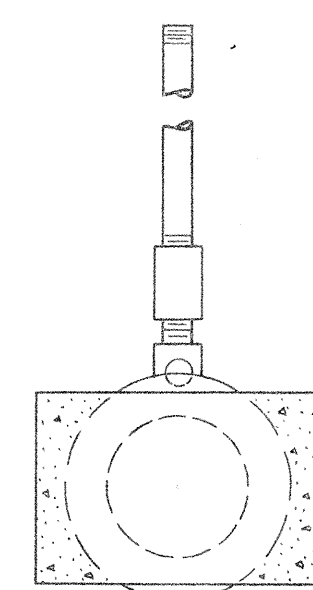


END VIEW

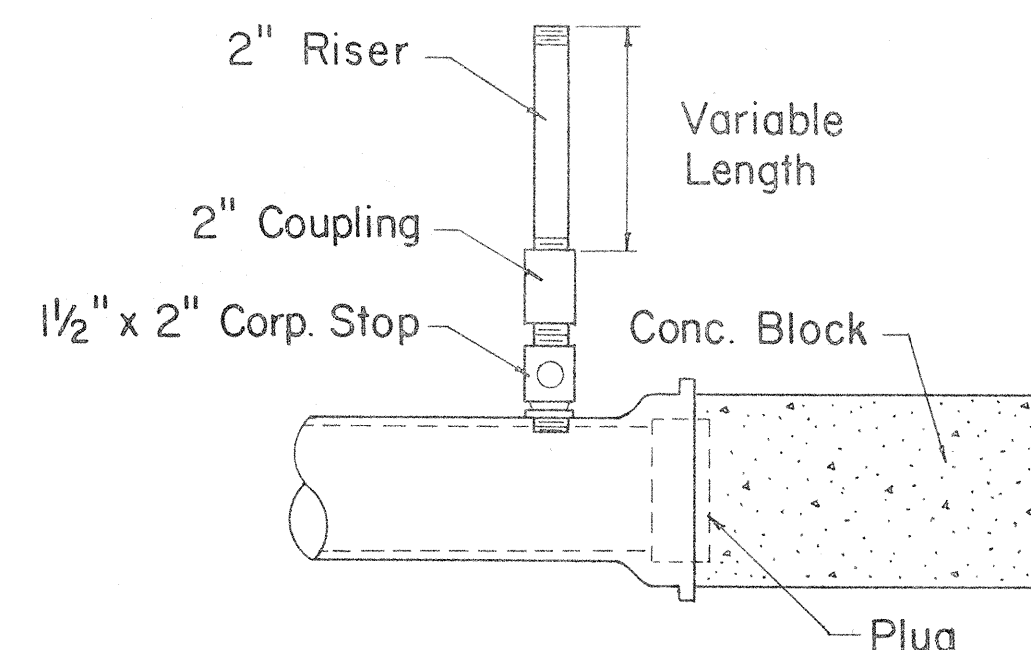


SIDE VIEW


DETAIL OF
TEMPORARY 2" CLEANOUT
Not to Scale

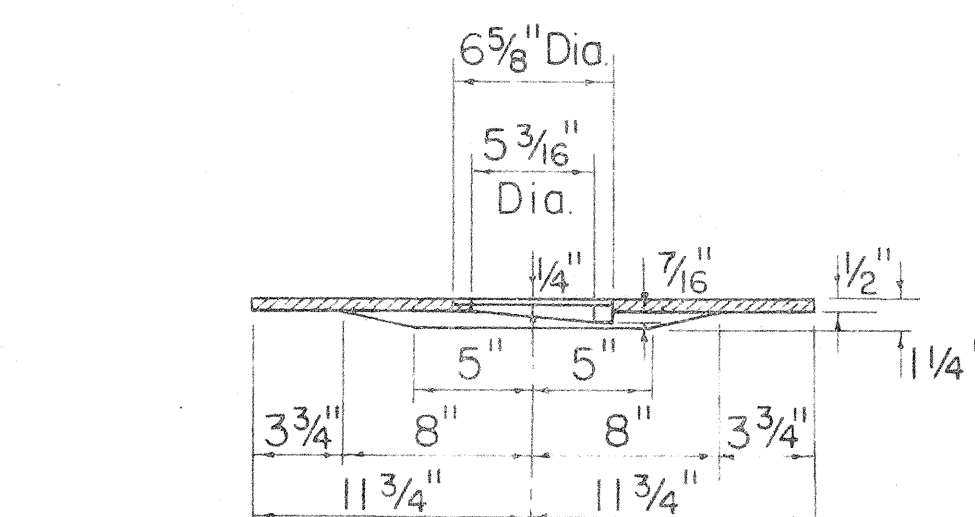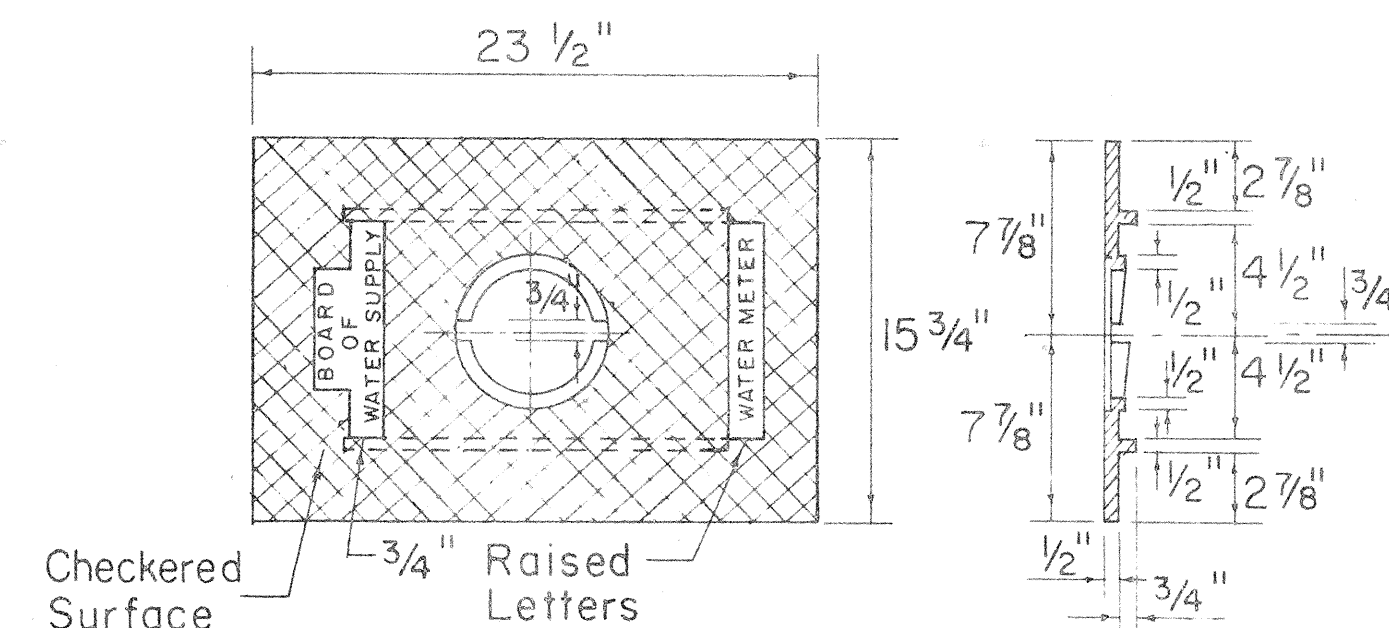

COVER PLATE

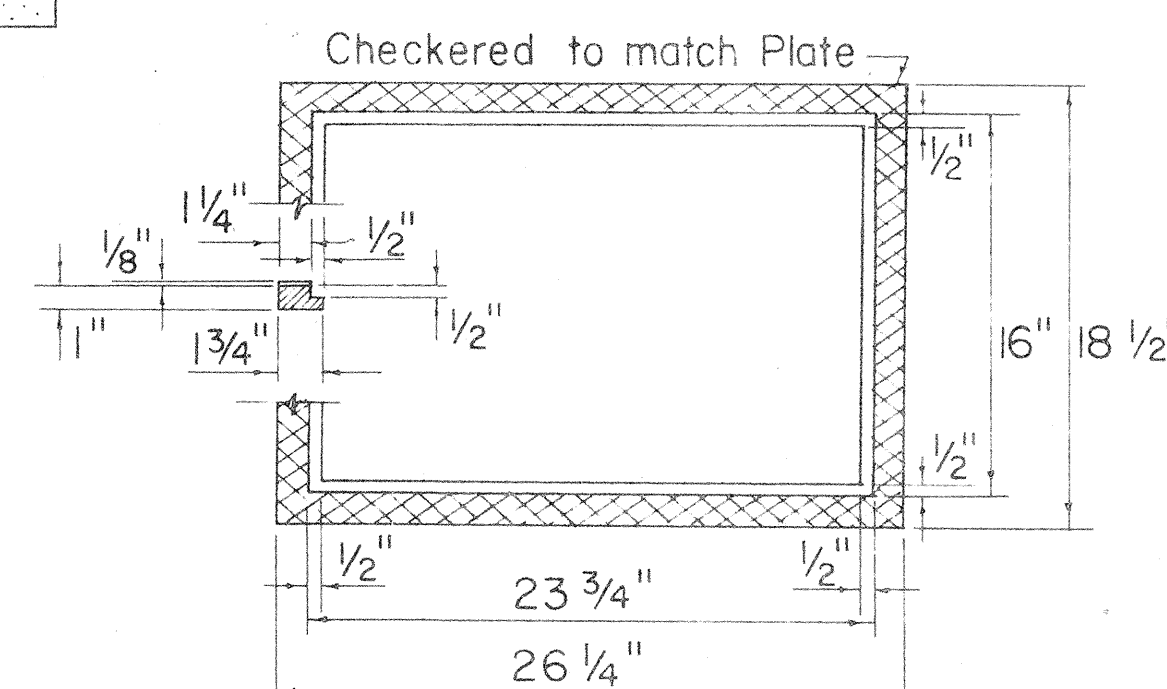



FRAME
CAST IRON FRAME AND PLATE
TYPE II
Scale: 1/2" = 1'-0"

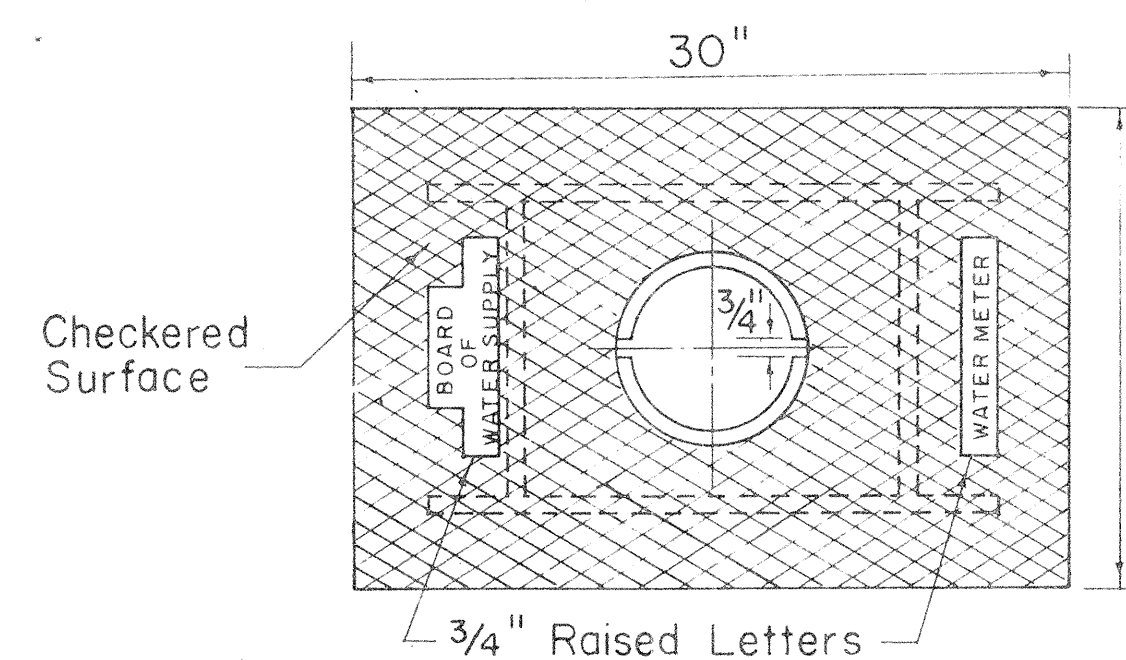

COVER PLATE


CAST IRON FRAME, PLATE AND COVER

TYPE III
Scale: 1/2" = 1'-0"

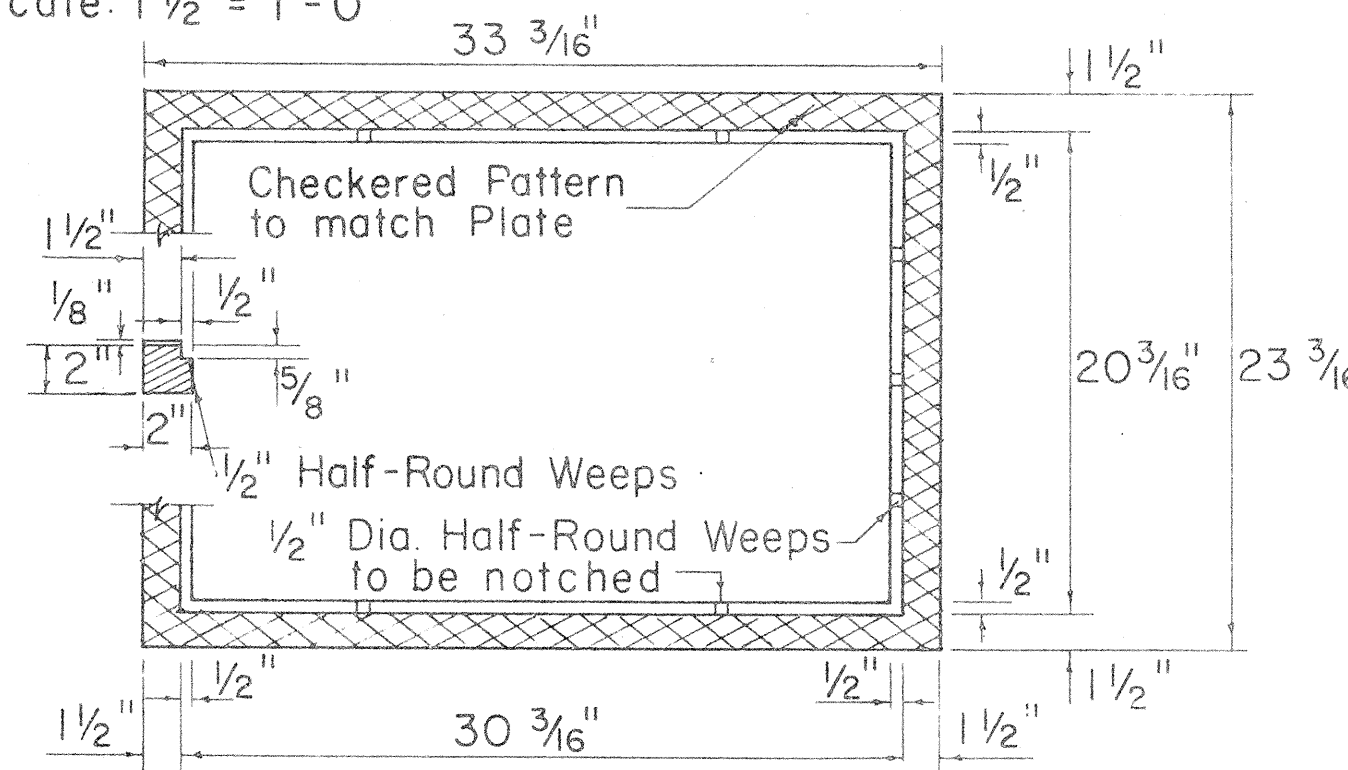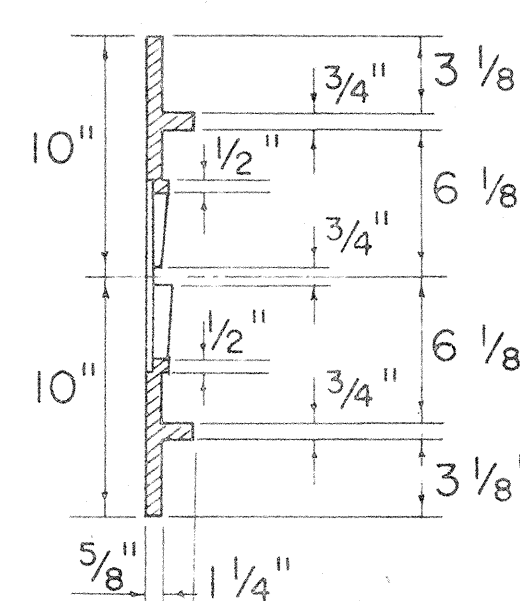


FRAME


READING COVER

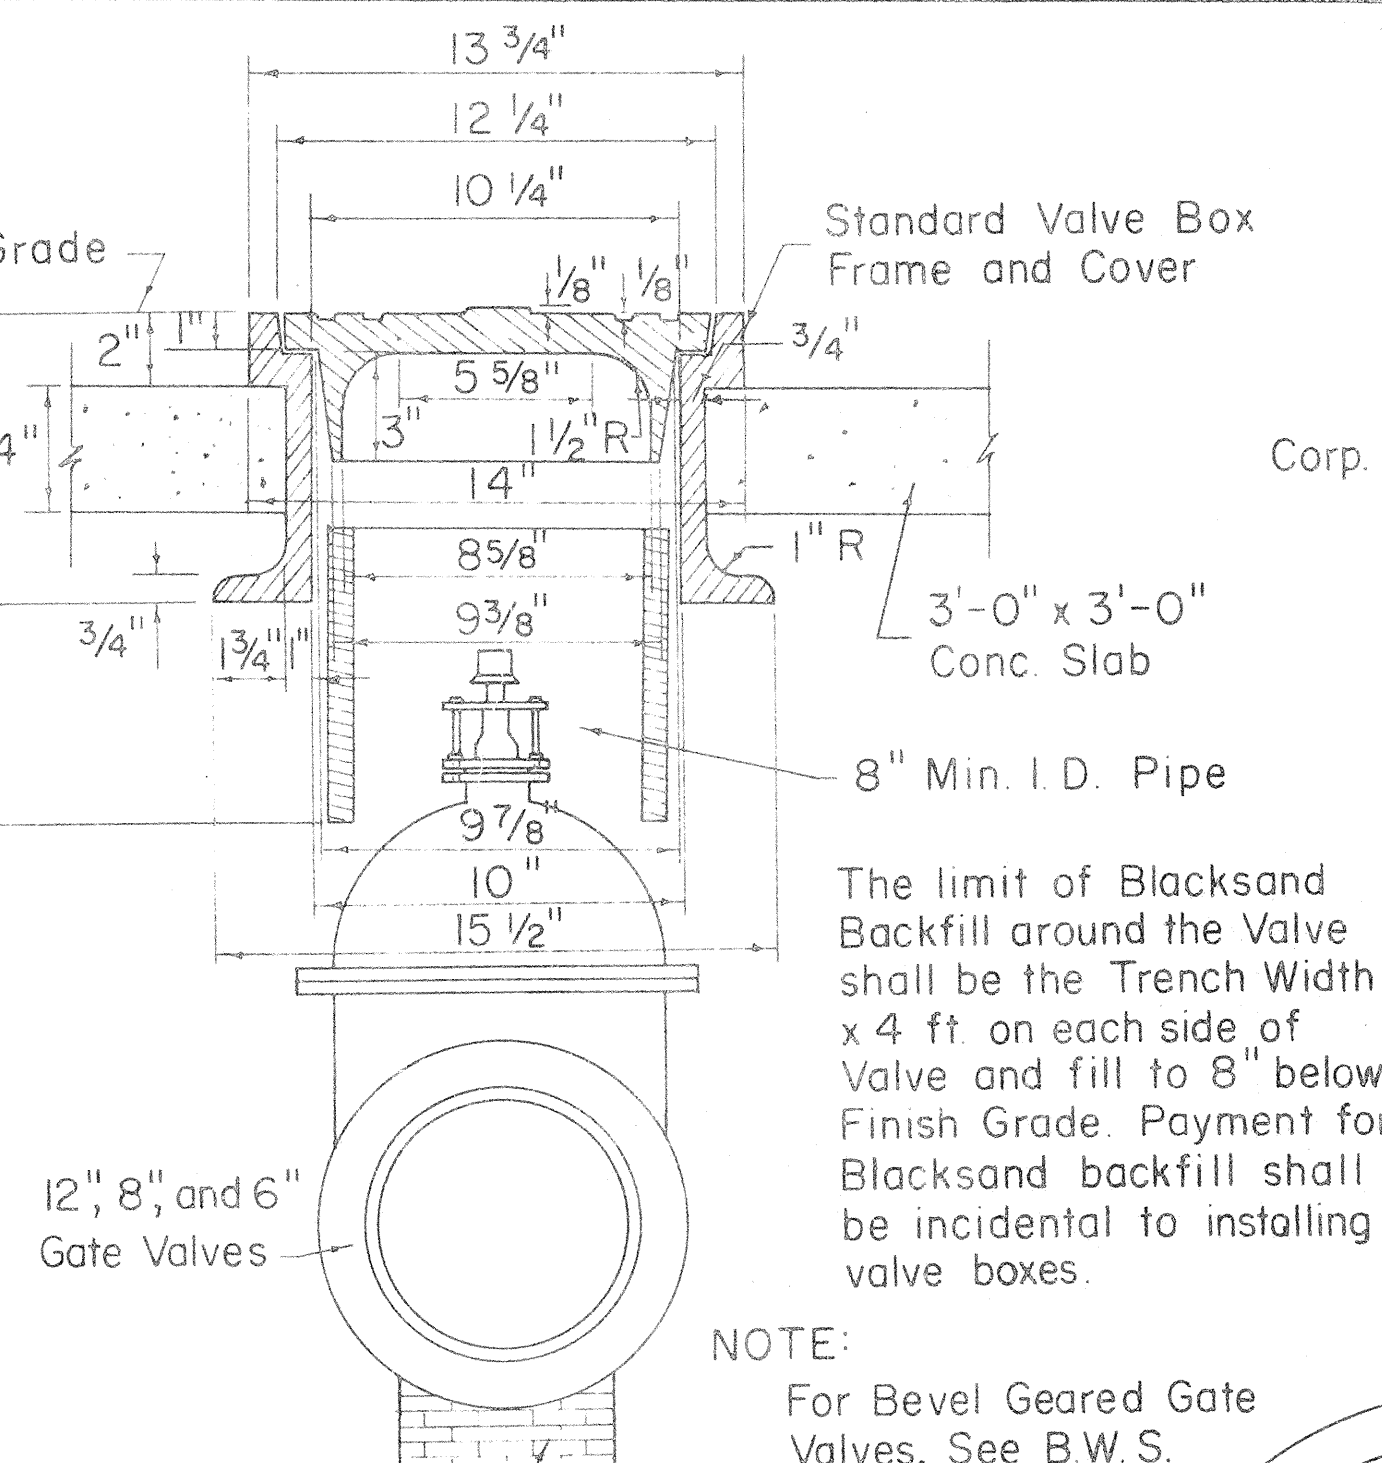


INSTALLATION OF VALVE
BOX FOR GATE VALVES
Not to Scale

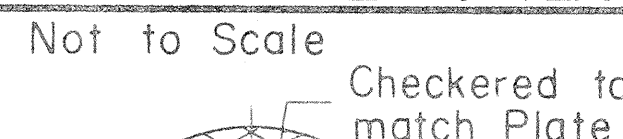

Checkered to match Plate

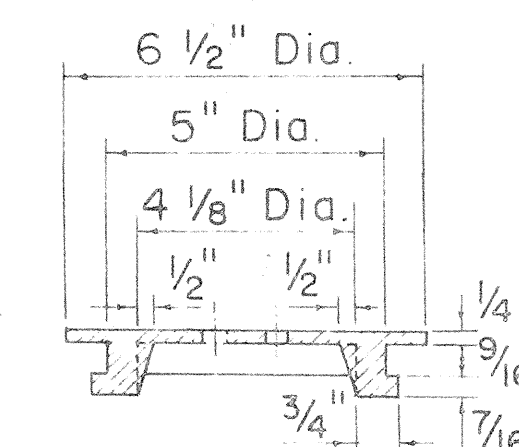


READING COVER

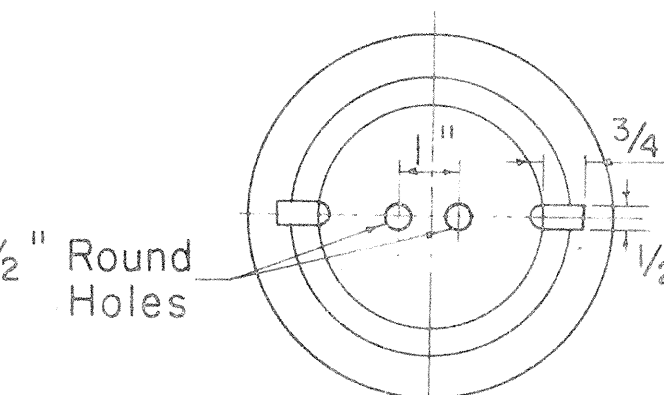


CHECKERED PATTERN

CAST IRON COVER FOR
TYPE II FRAME
Not to Scale

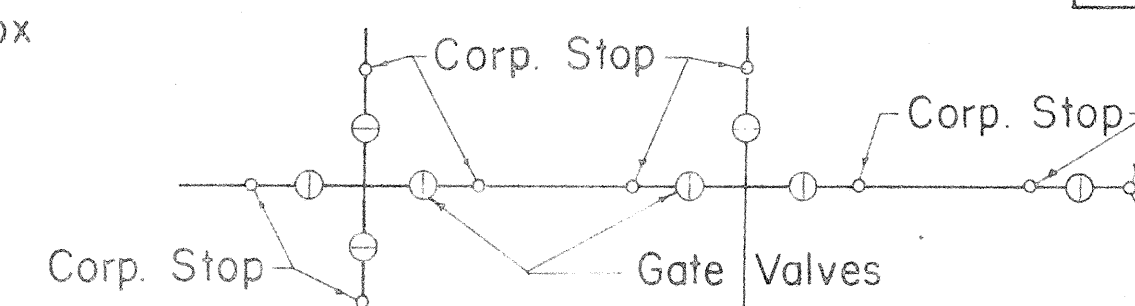


CORP. STOP LAYOUT
Not to Scale

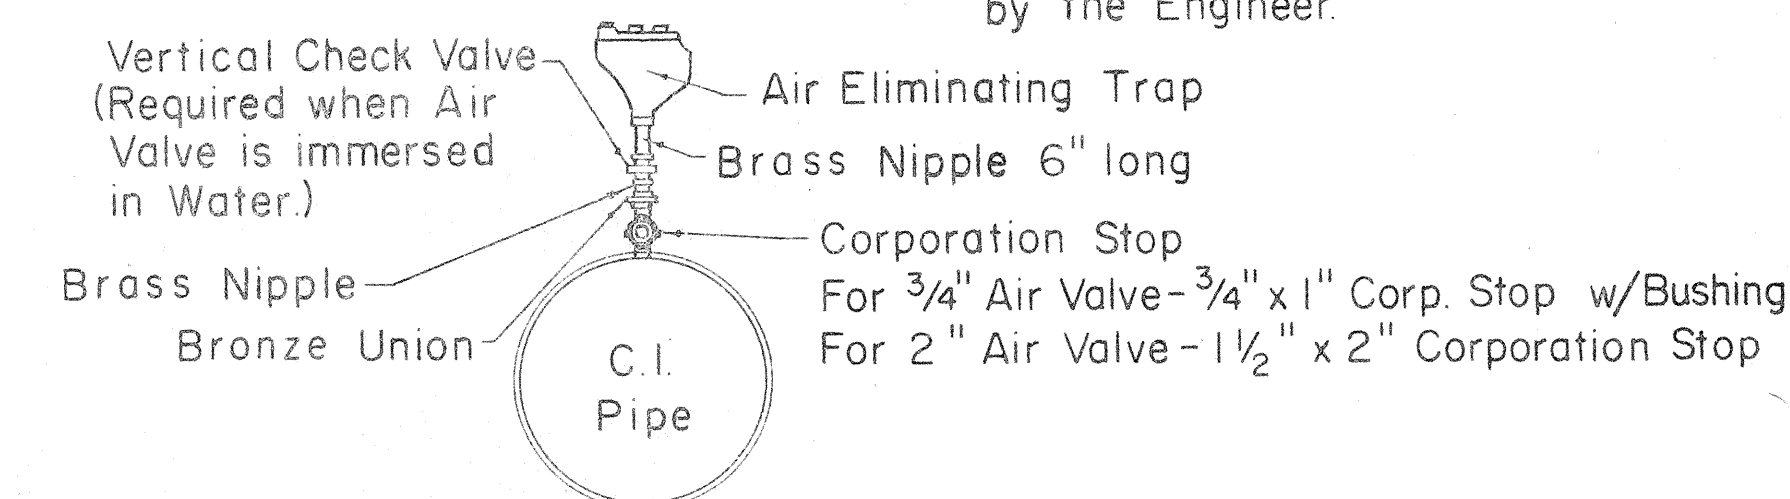


DETAIL OF CONNECTION FOR
AIR ELIMINATING TRAP
Not to Scale

Offset word "WATER" 1 3/4" high, 1/8" deep

NOTE:
All castings shall be made accurately to the dimensions shown. Seat and Cover shall be ground where necessary to secure flat and true surfaces. The Cover shall not rattle in any position.
Minor changes in dimensions may be made to suit foundry conditions provided such changes are approved by the Board of Water Supply.

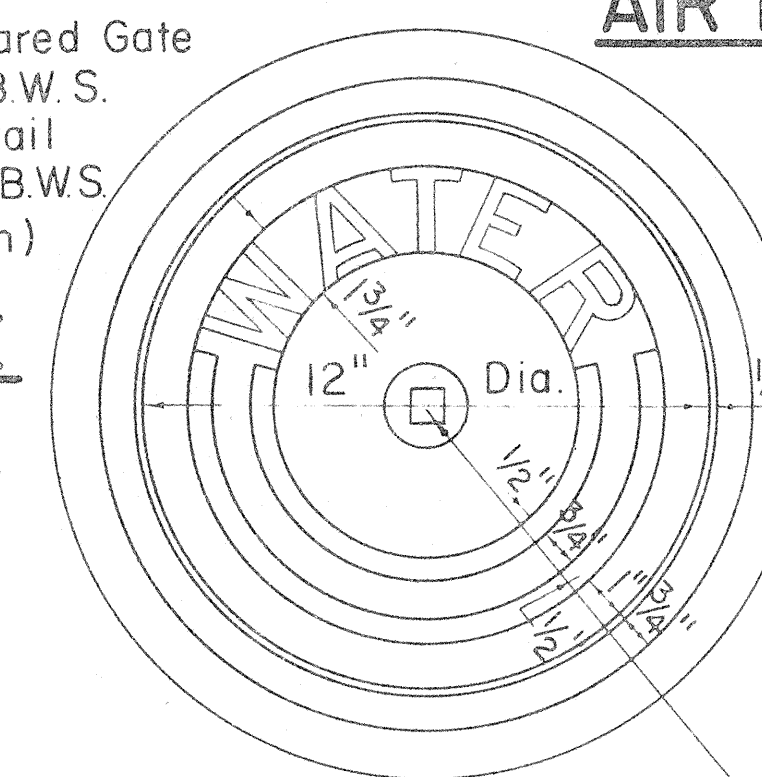

CAST IRON FRAME AND COVER
Scale: 3" = 1'-0"

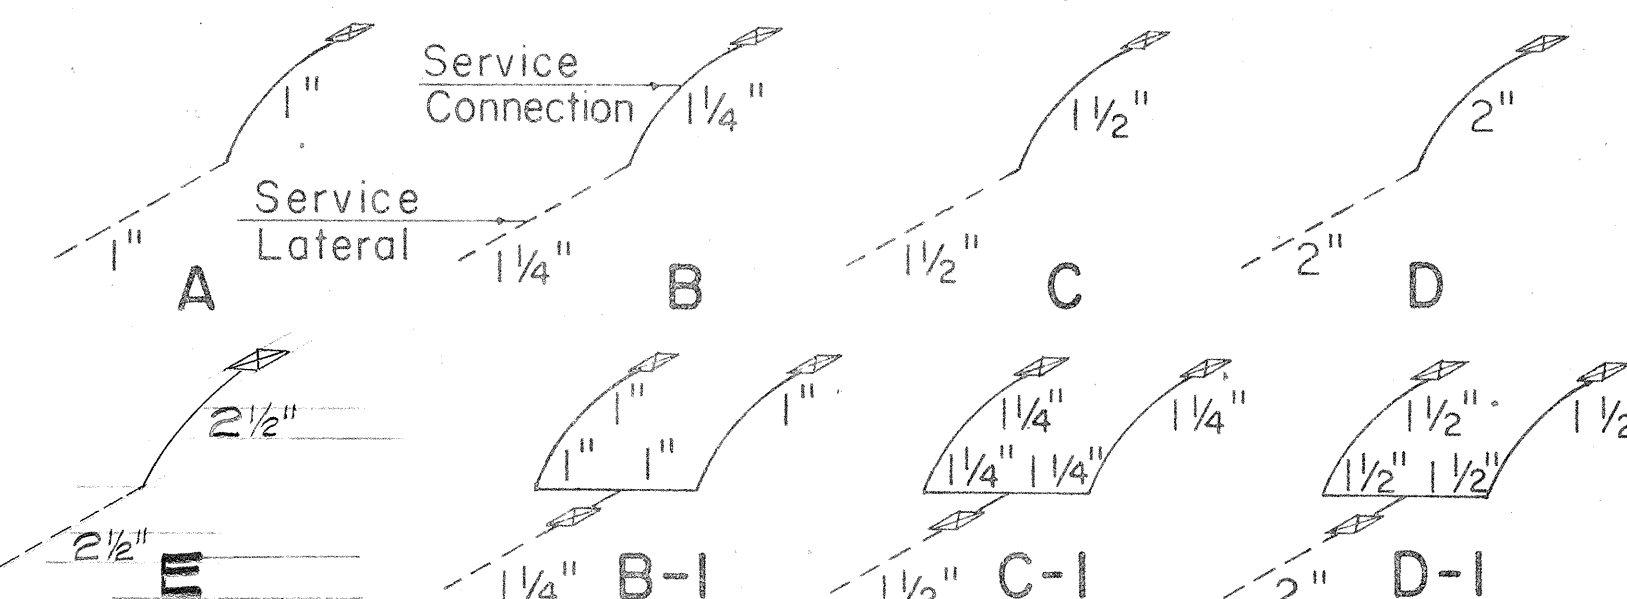


TYPICAL LAYOUT OF SERVICE
LATERALS AND CONNECTIONS
Not to Scale

APPROVED:


A. Kawapuni
CHIEF, ENGINEERING DIVISION
BOARD OF WATER SUPPLY

STATE OF HAWAII
DEPARTMENT OF TRANSPORTATION
HIGHWAYS DIVISION
BOARD OF WATER SUPPLY
CITY & COUNTY OF HONOLULU
STANDARD WATER DETAILS
INTERSTATE ROUTE H-1
PROJ. NO. I-HI(66)11
Scale: As Noted Date 8/16/68



SHEET NO. 11 OF 27 SHEETS

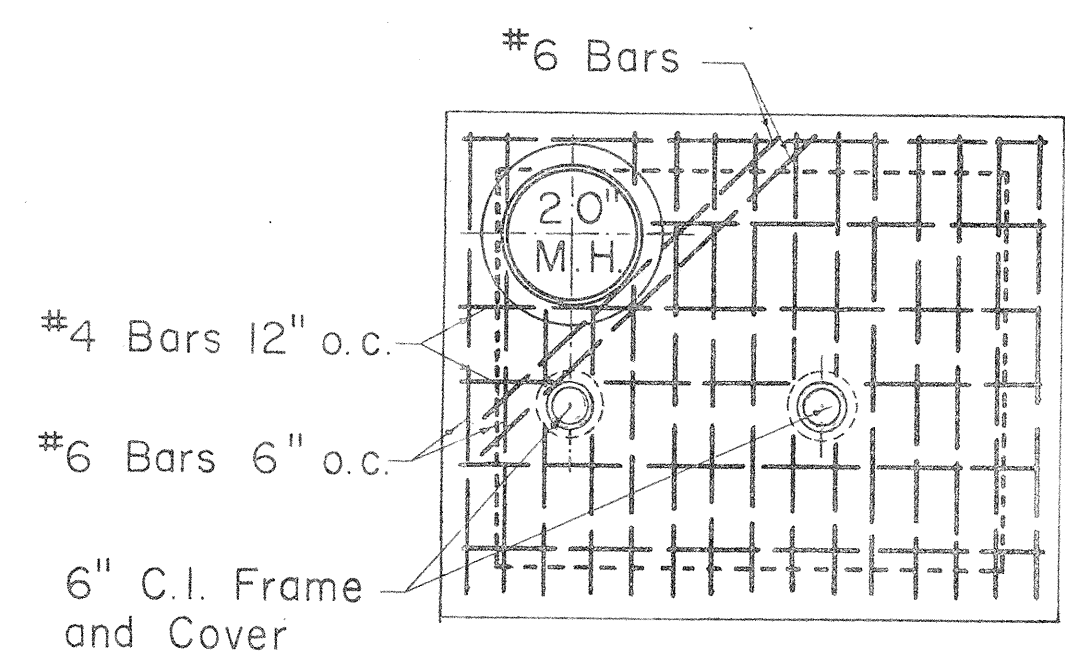




PLAN OF TOP SLAB

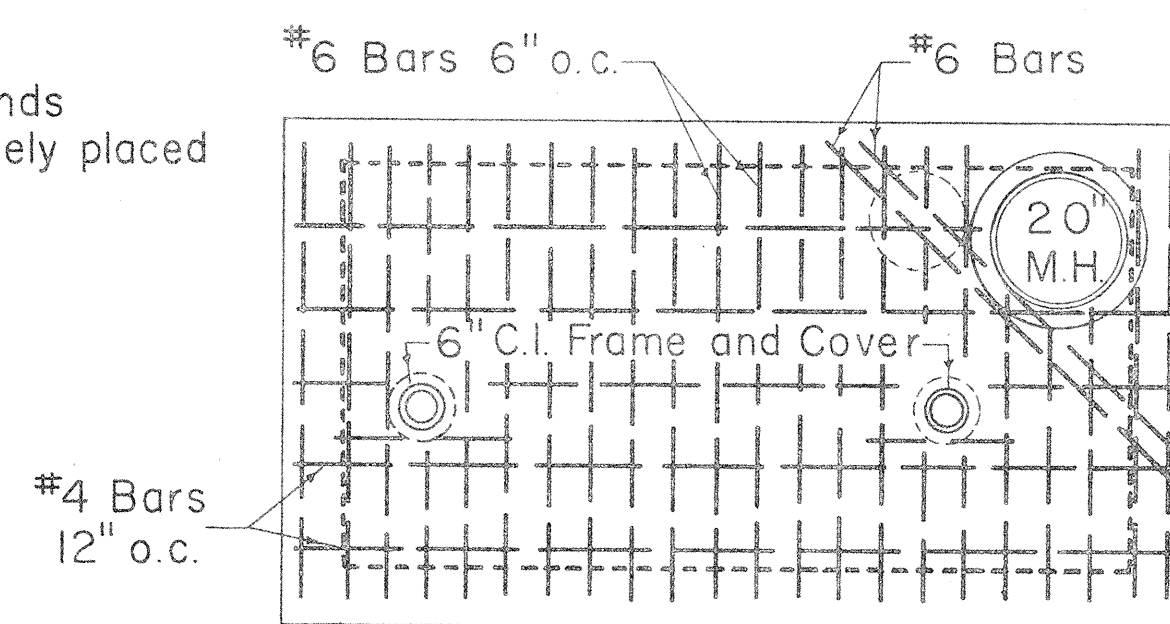

PLAN OF TOP SLAB

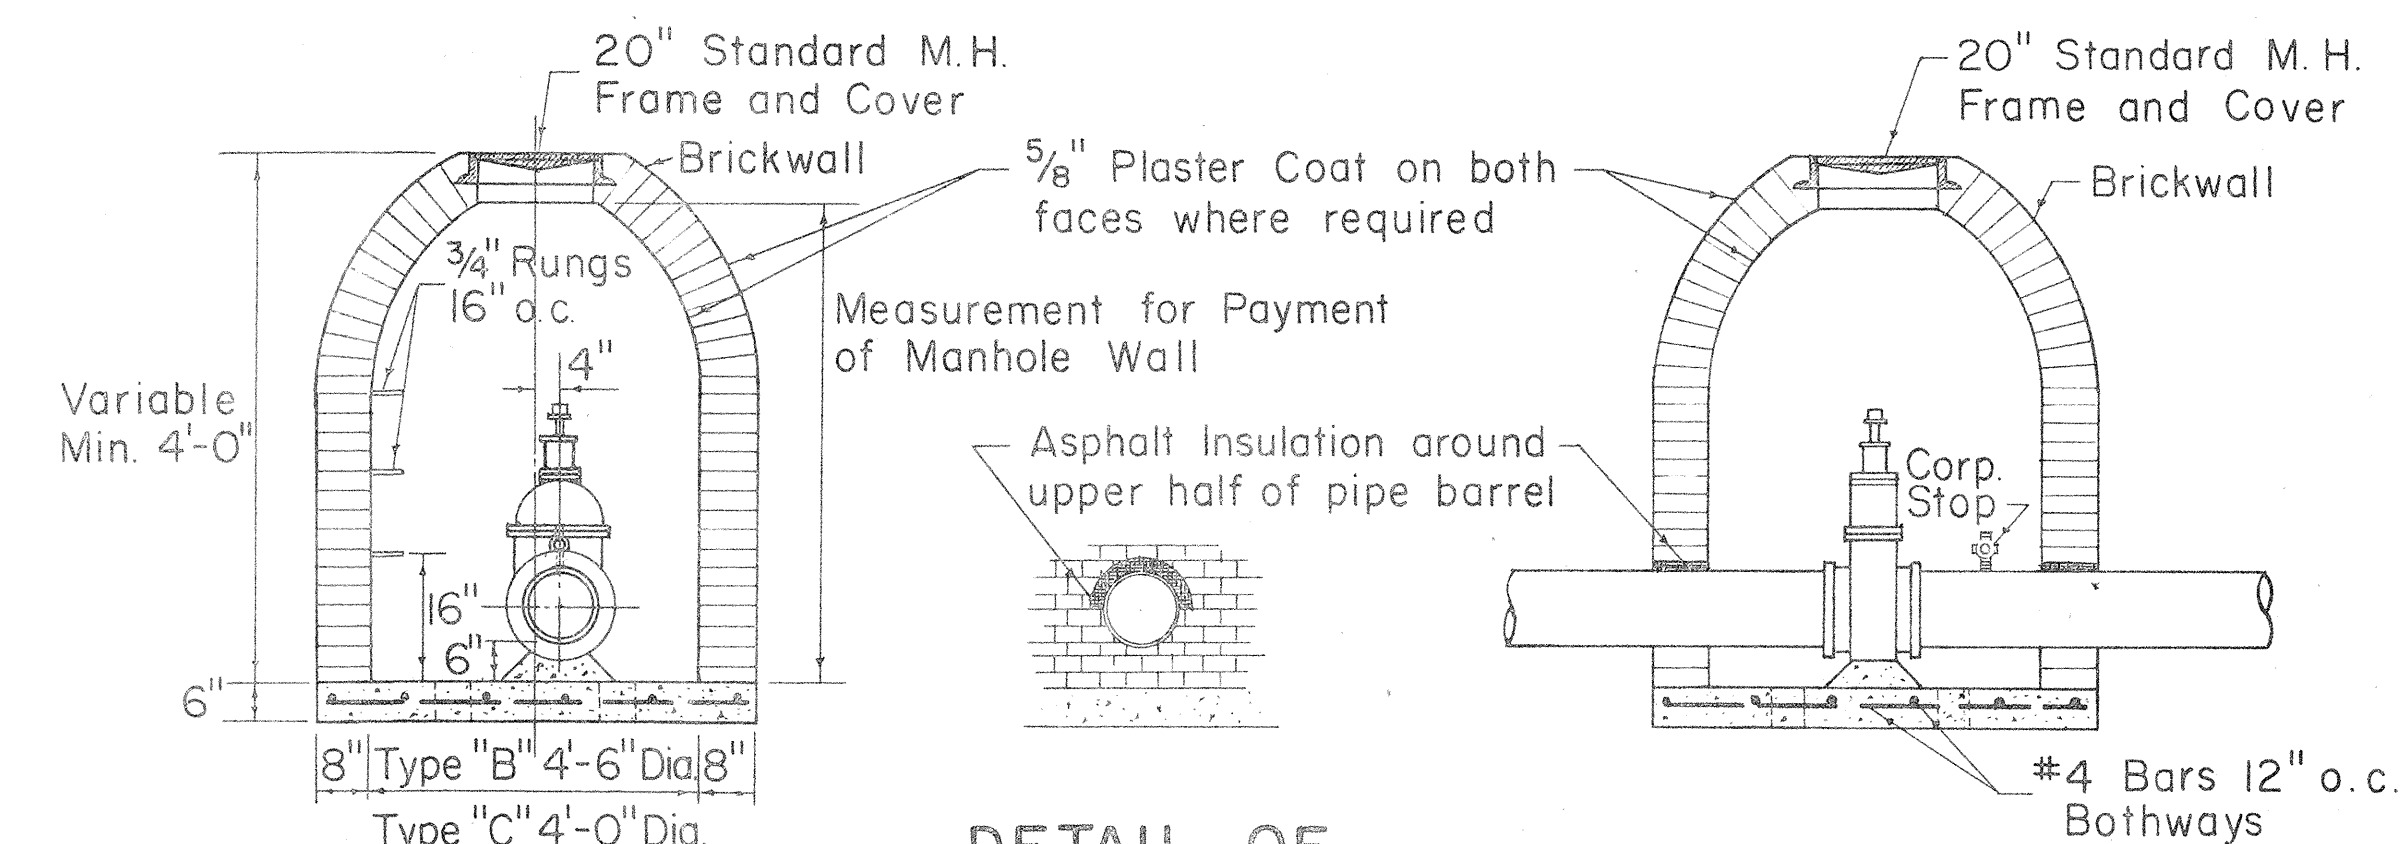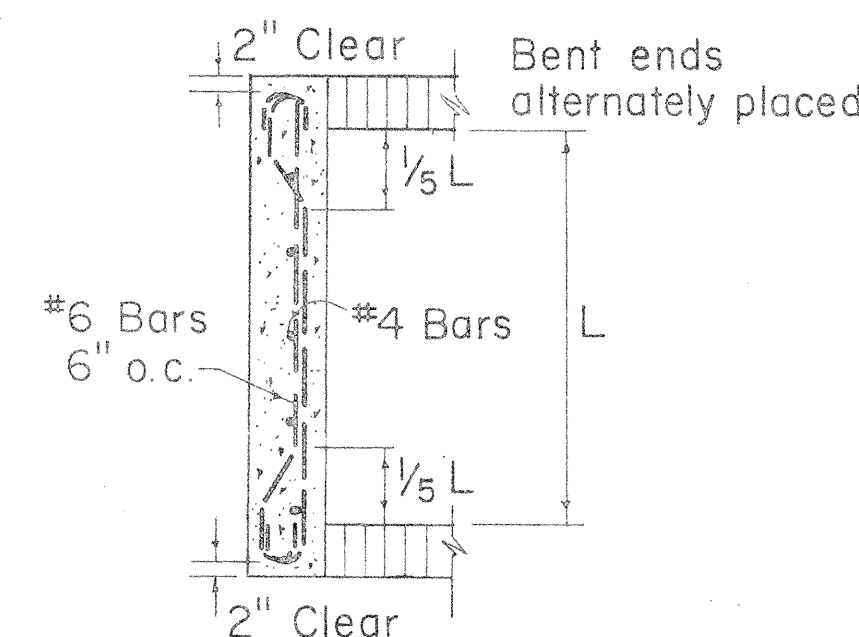


DETAIL OF ASPHALT FILLER

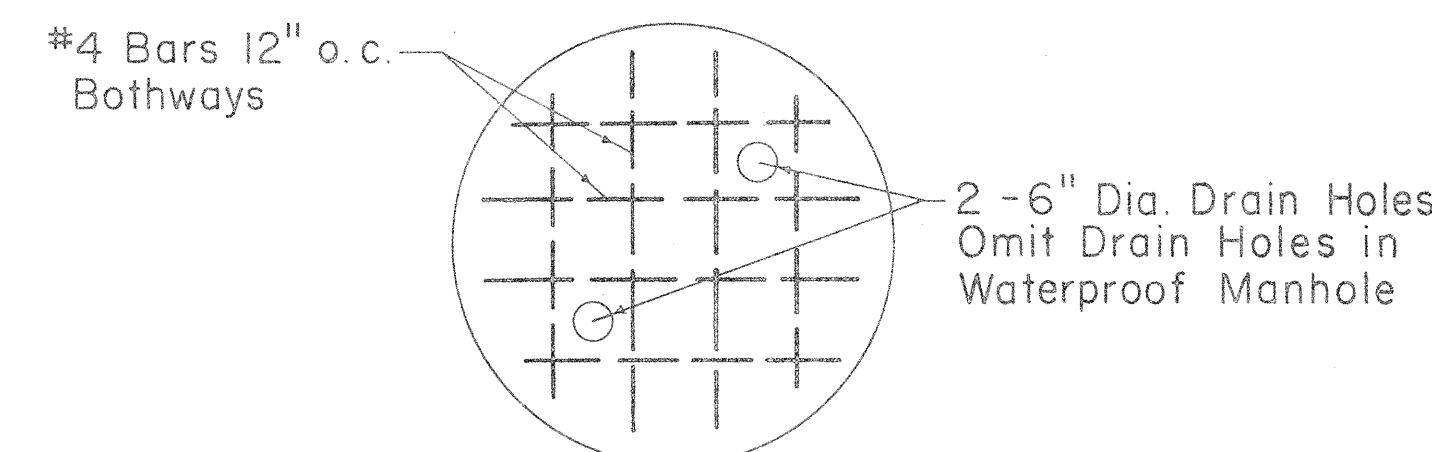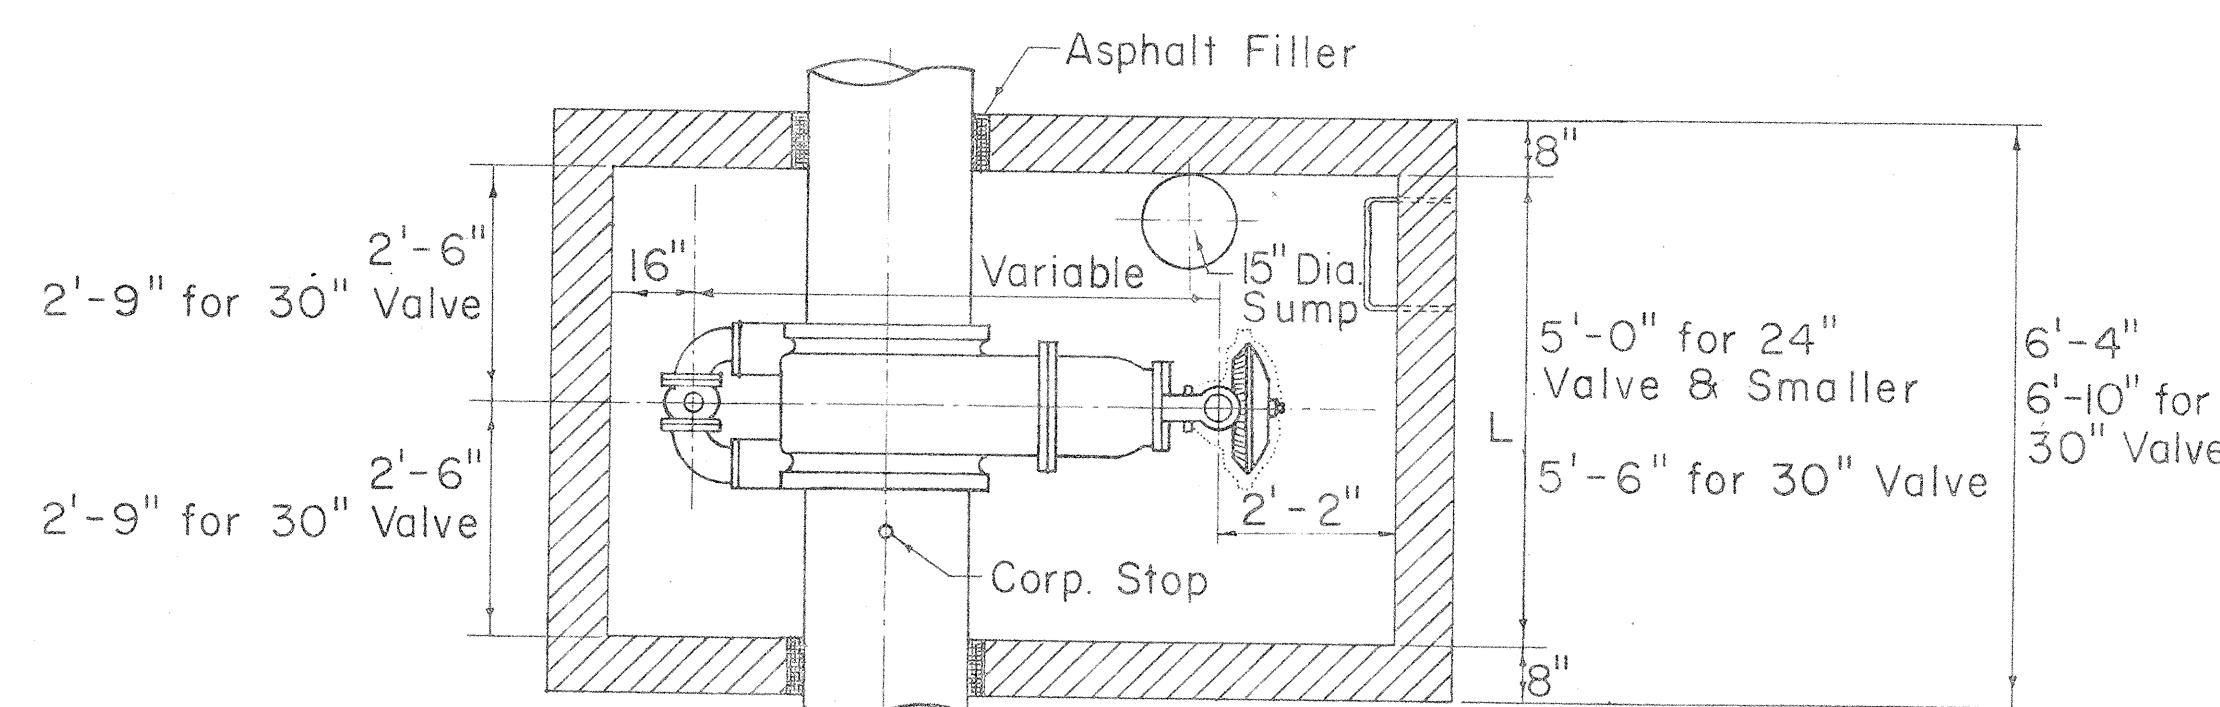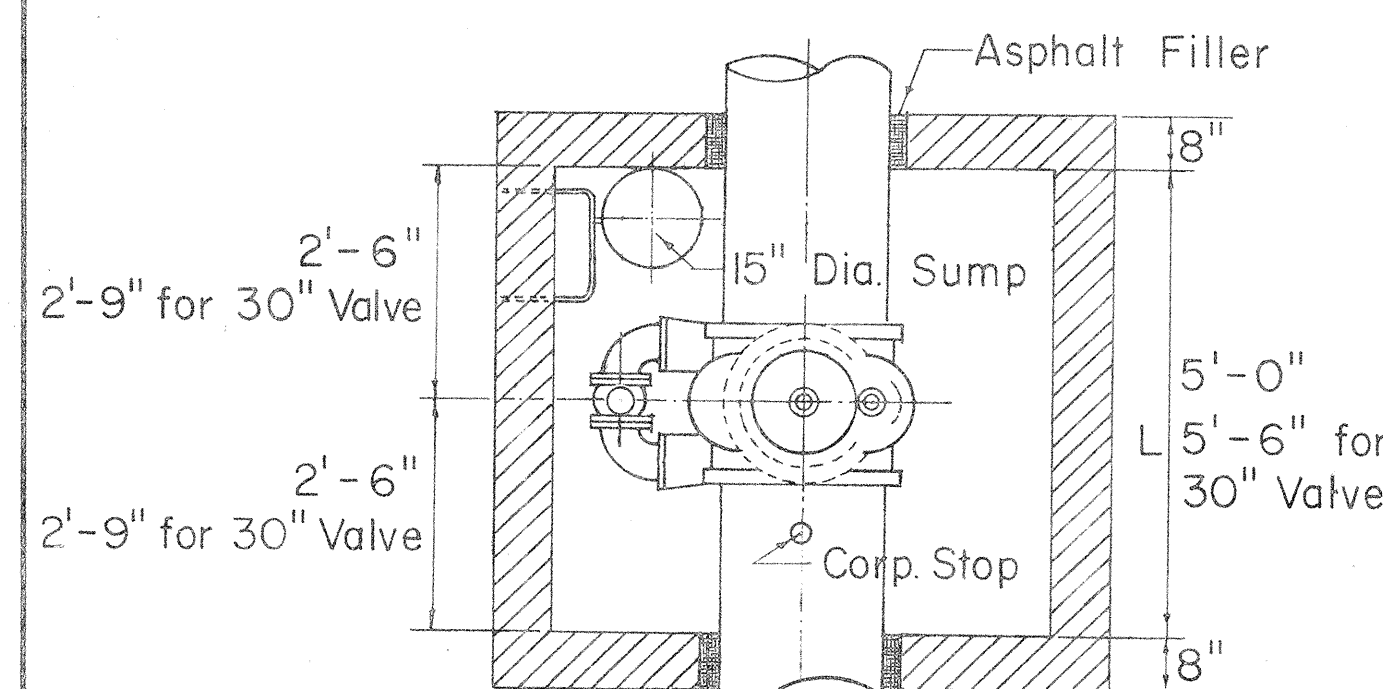


STEEL DETAIL IN BOTTOM SLAB

TABLE "A"
REQUIRED CORPORATION STOP SIZES
AT GATE VALVE


DIA. OF MAIN INCHES	SIZE OF CORP STOP
4	1" x 1 1/4"
6	1" x 1 1/4"
8	1" x 1 1/4"
12	1" x 1 1/4"
16	1" x 1 1/4"
20	1" x 1 1/4"
24	1 1/2" x 2"
36	1 1/2" x 2"
42	1 1/2" x 2"

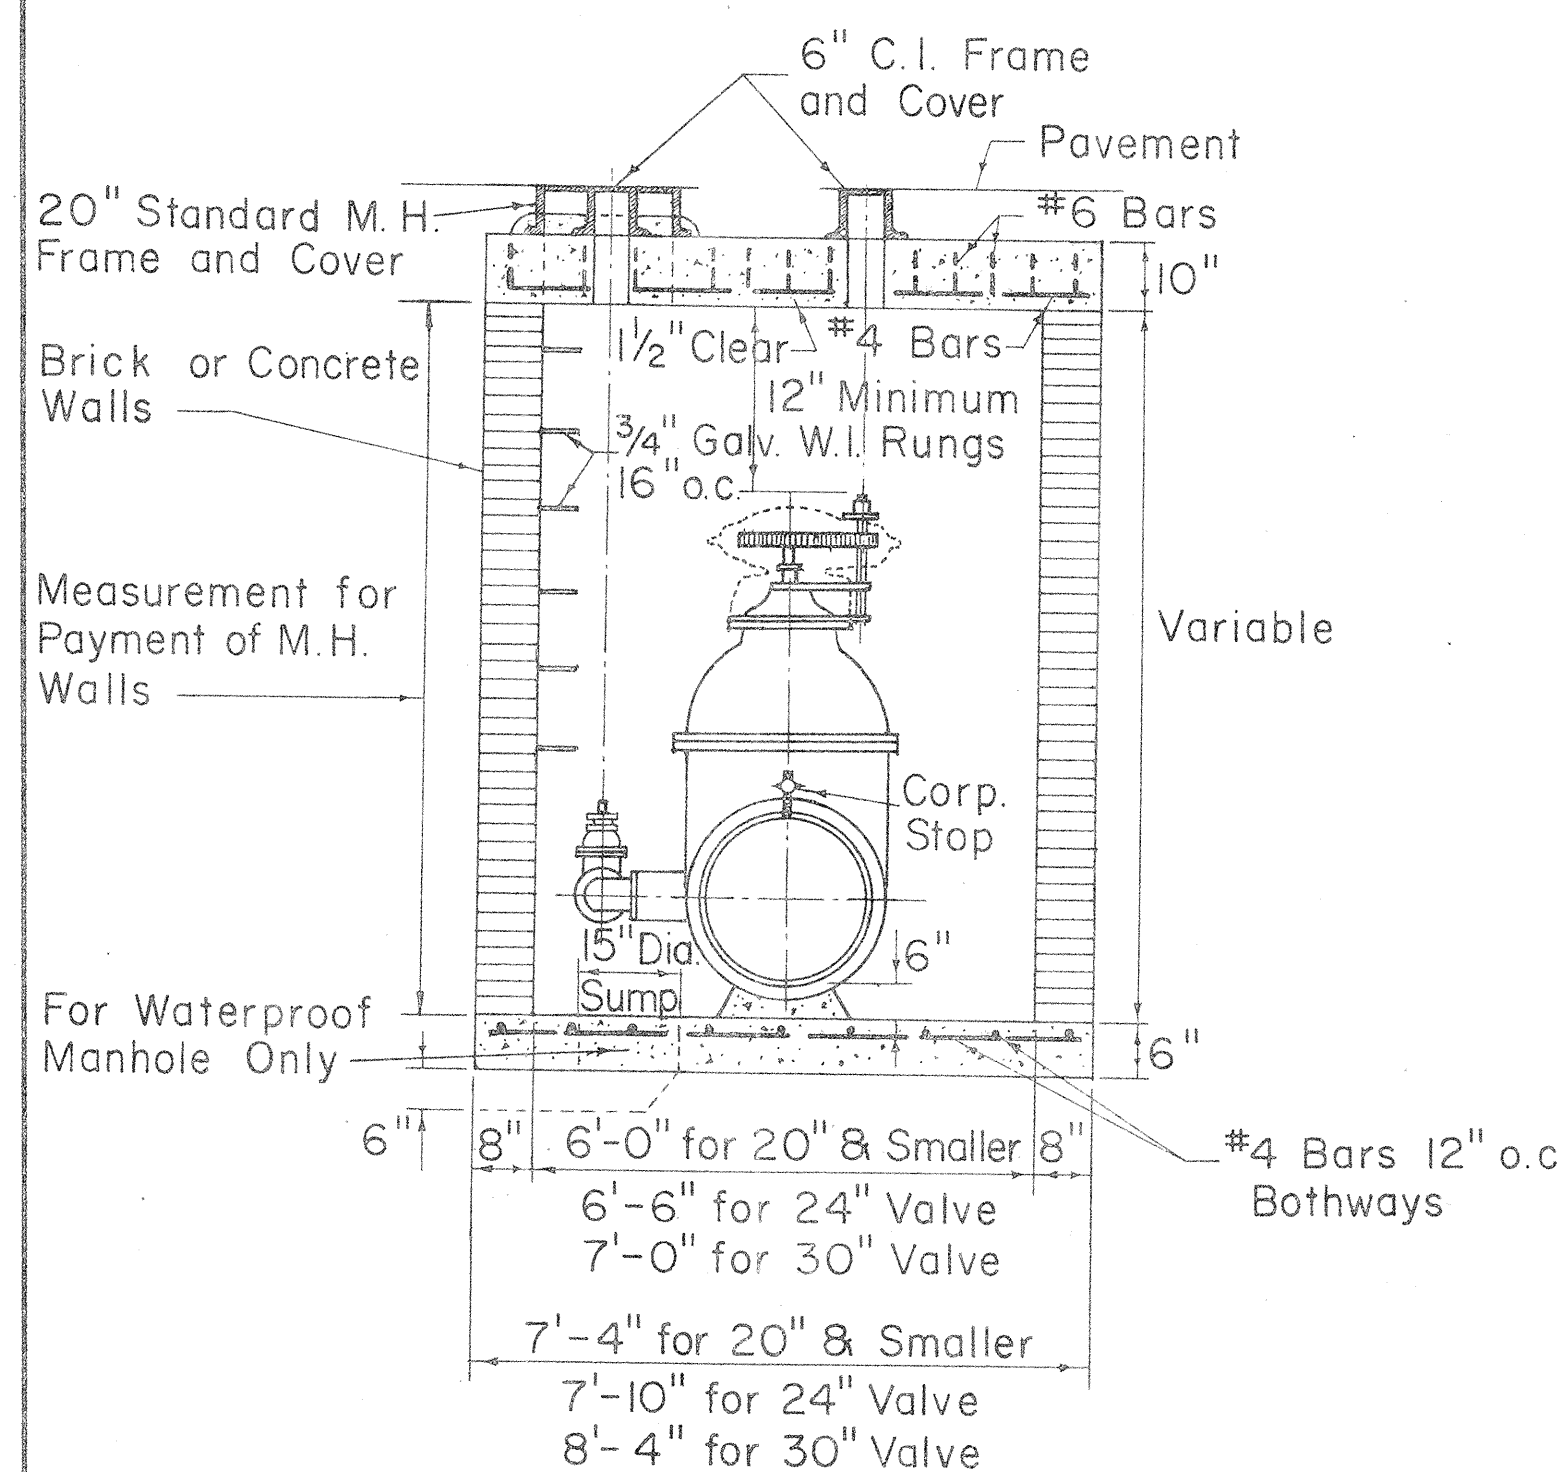


SECTION
TYPE "A" MANHOLE
FOR SPUR GEARED GATE VALVES

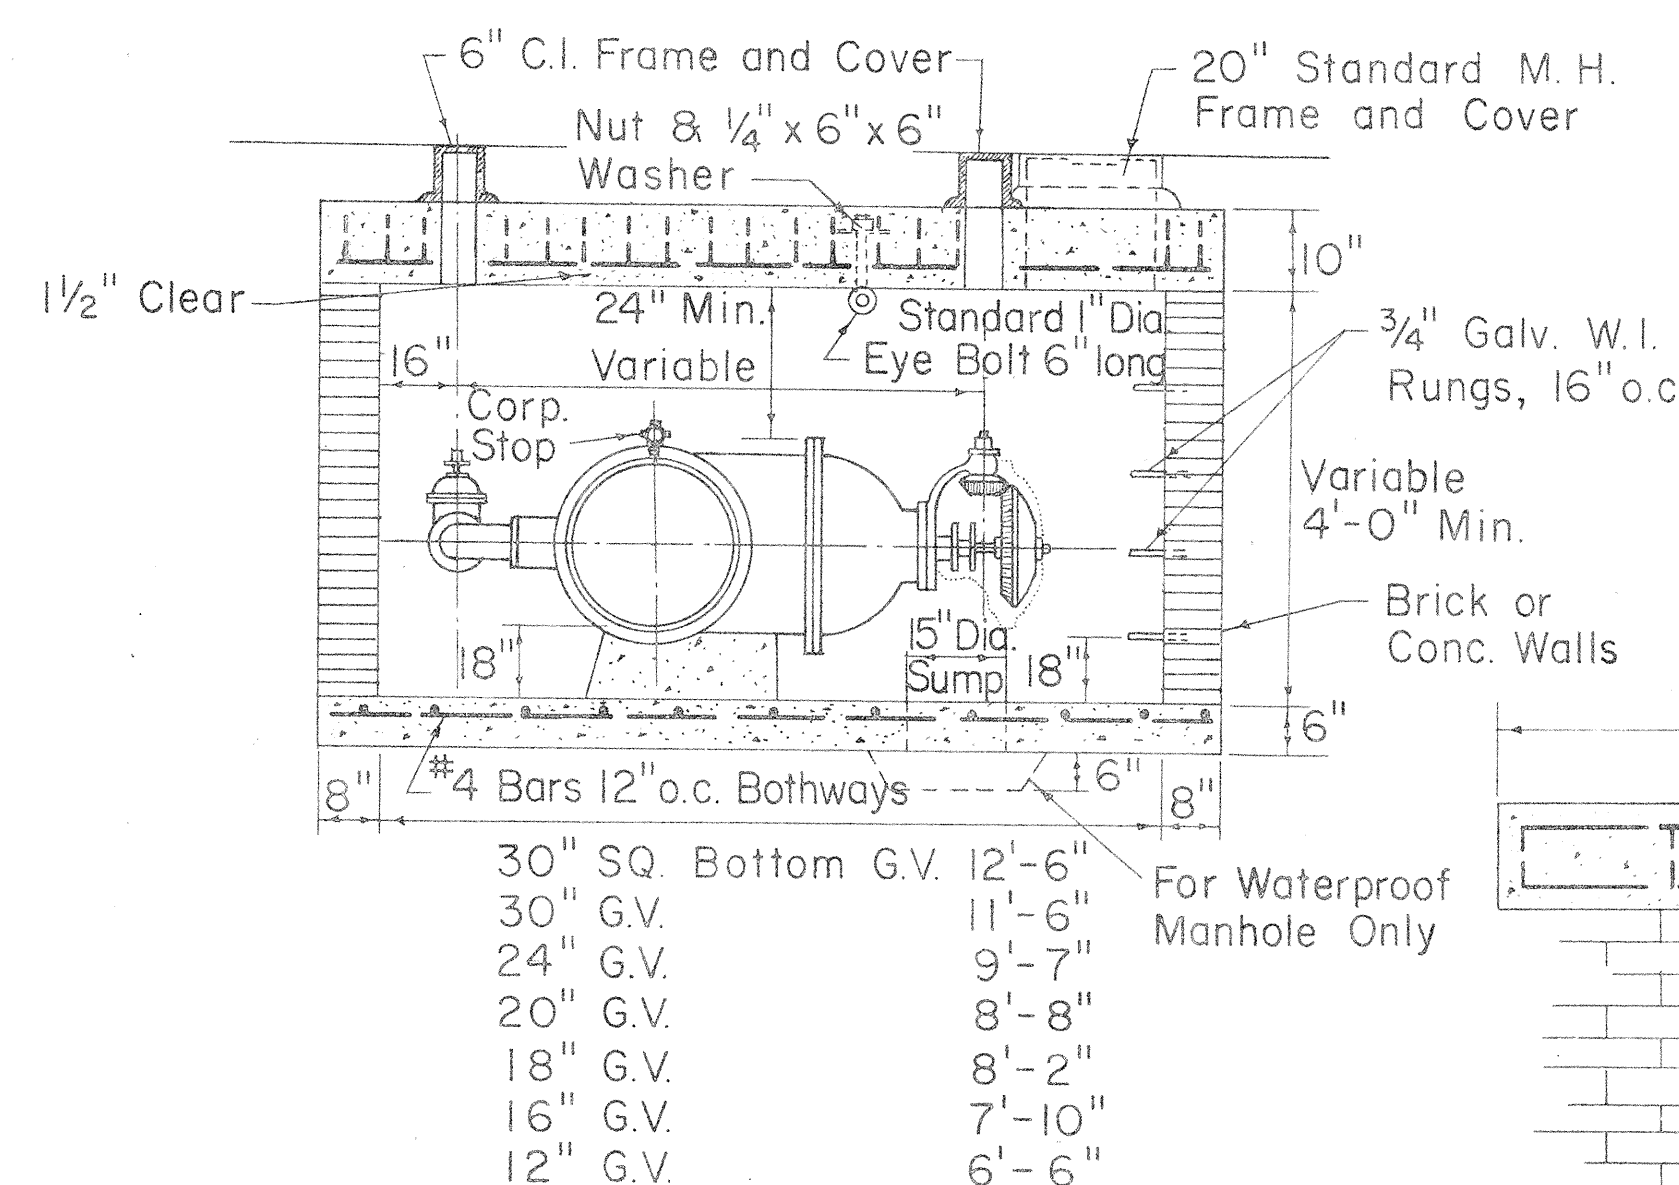


SECTION
TYPE "A" MANHOLE
FOR BEVEL GEARED GATE VALVES

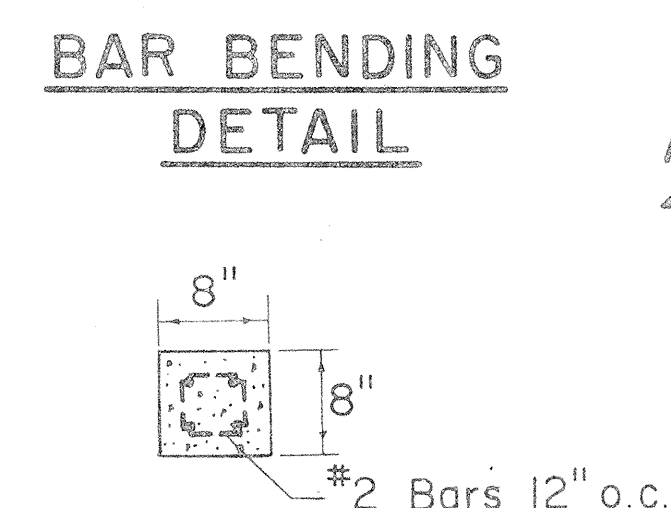


BAR BENDING
DETAIL

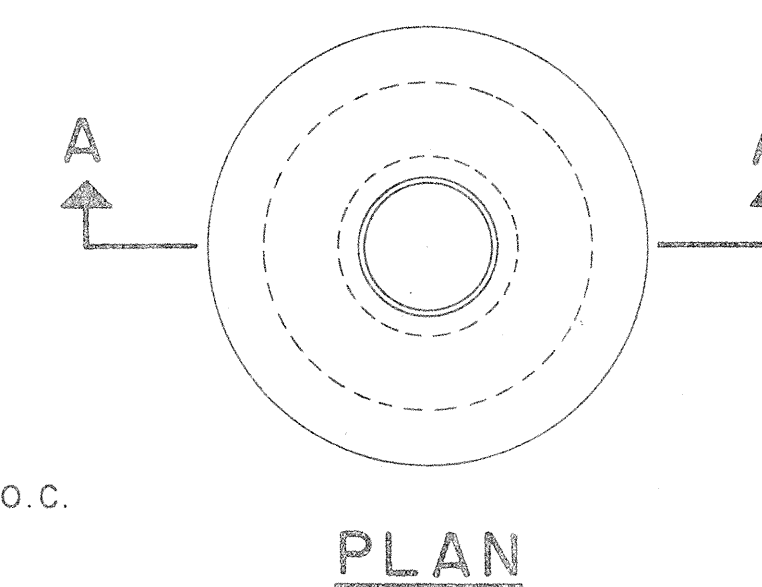

PLAN

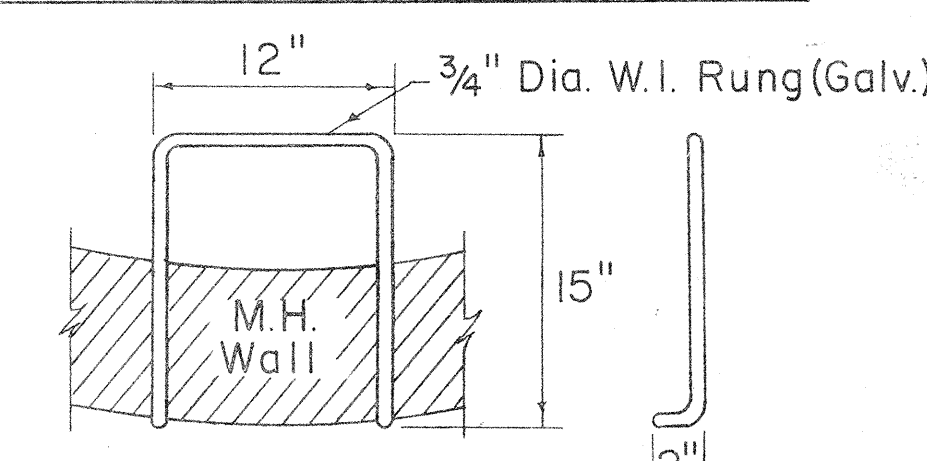

DETAIL OF RUNG

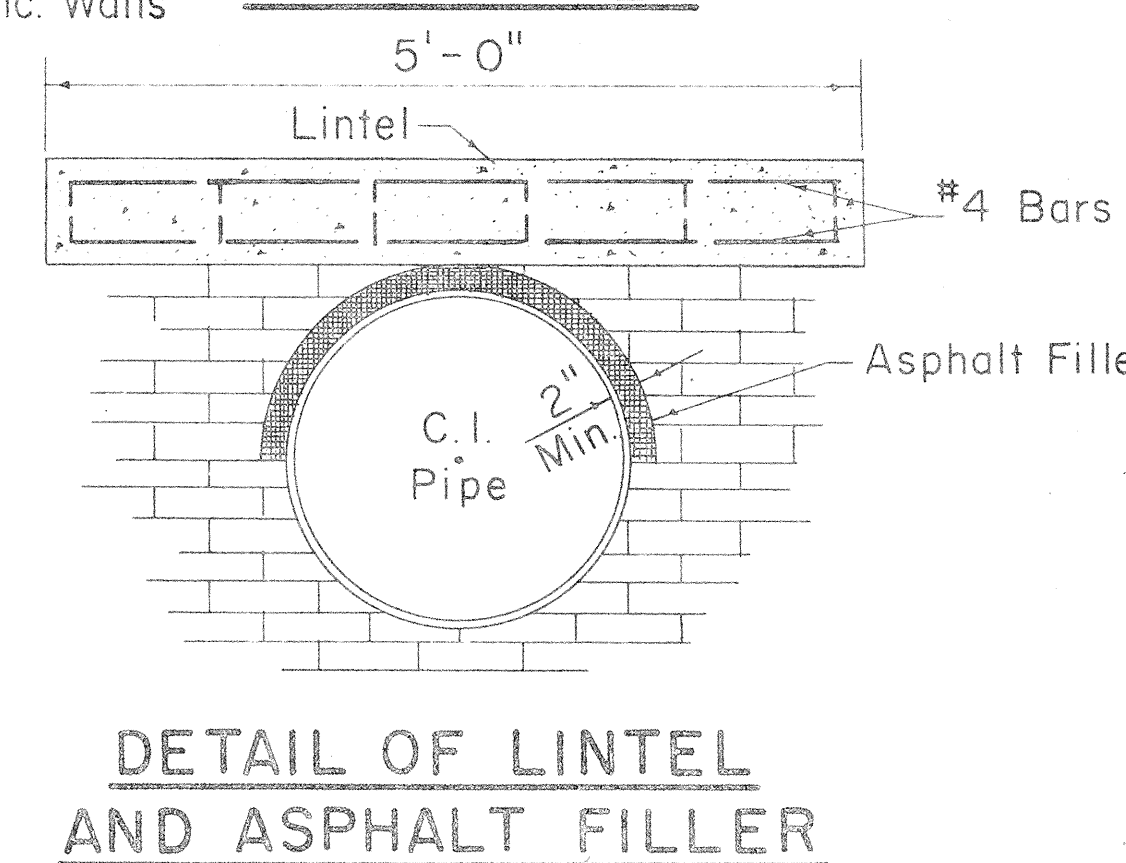

DETAIL OF LINTEL
AND ASPHALT FILLER


TYPE "B" AND "C" MANHOLES
TYPE "B" 4'-6" DIA. (FOR 12" G.V.)
TYPE "C" 4'-0" DIA. (FOR 6" & 8" G.V.)

APPROVED:

H. Kawasumi
CHIEF, ENGINEERING DIVISION
BOARD OF WATER SUPPLY




STATE OF HAWAII
DEPARTMENT OF TRANSPORTATION
HIGHWAYS DIVISION
BOARD OF WATER SUPPLY
CITY & COUNTY OF HONOLULU
STANDARD WATER DETAILS
INTERSTATE ROUTE H-1
PROJ. NO. I-H-1(6):11
Not to Scale Date 8/12/68
SHEET NO. 12 OF 27 SHEETS

FED. ROAD DIST. NO.	STATE	FED. AID PROJ. NO.	FISCAL YEAR	SHEET NO.	TOTAL SHEETS
HAWAII	HAW.	I-H-1(164)12 UNIT 2 I-H-1(16)11	1969	61	128

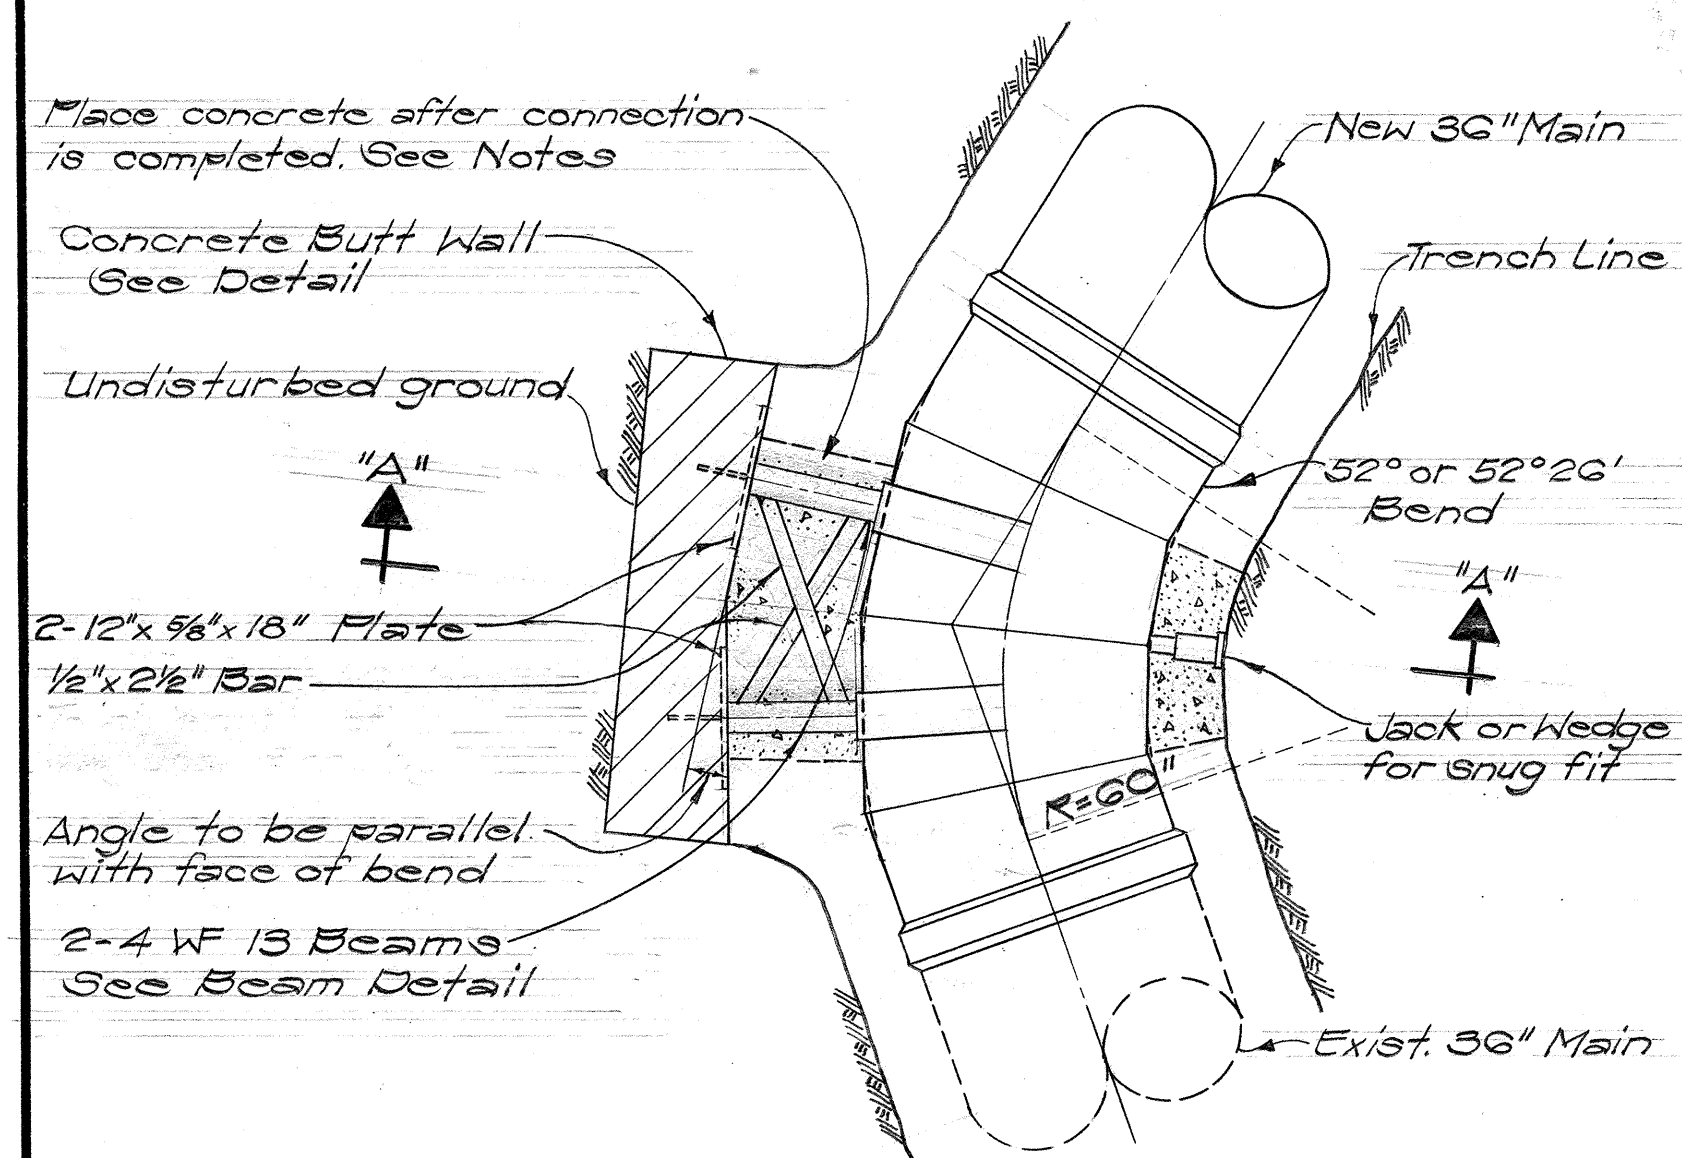


TYPICAL PLAN
Scale: 1/2" = 1'-0"


DETAIL OF VALVE MARKER
Scale: 1/2" = 1'-0"

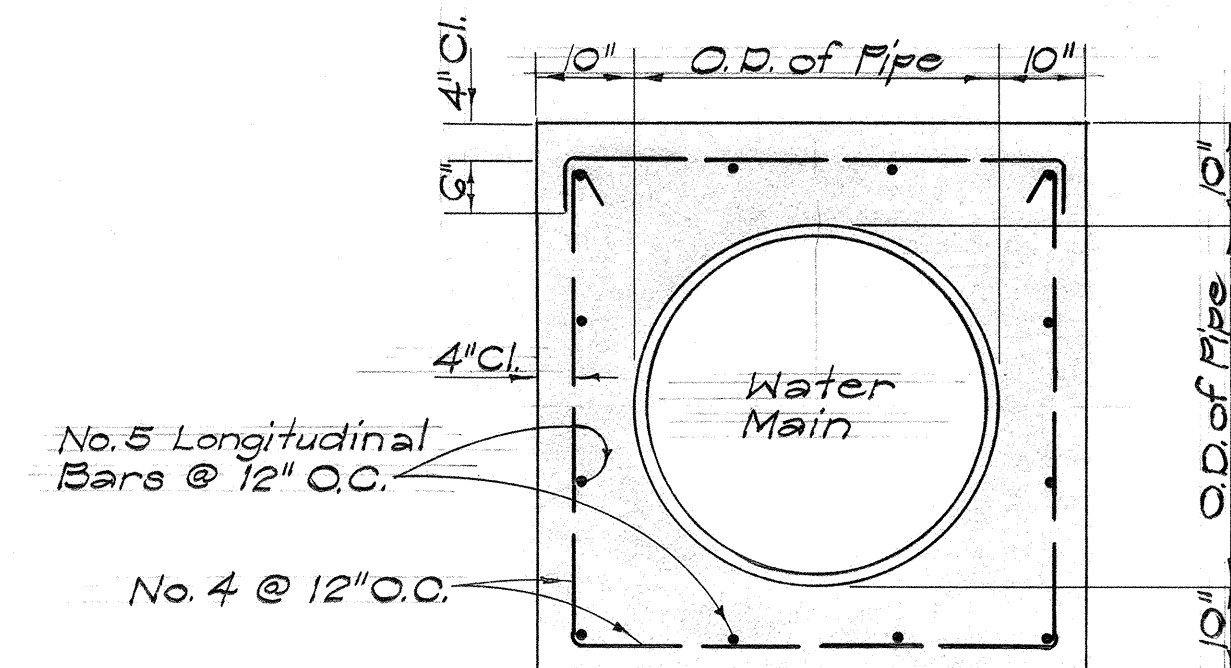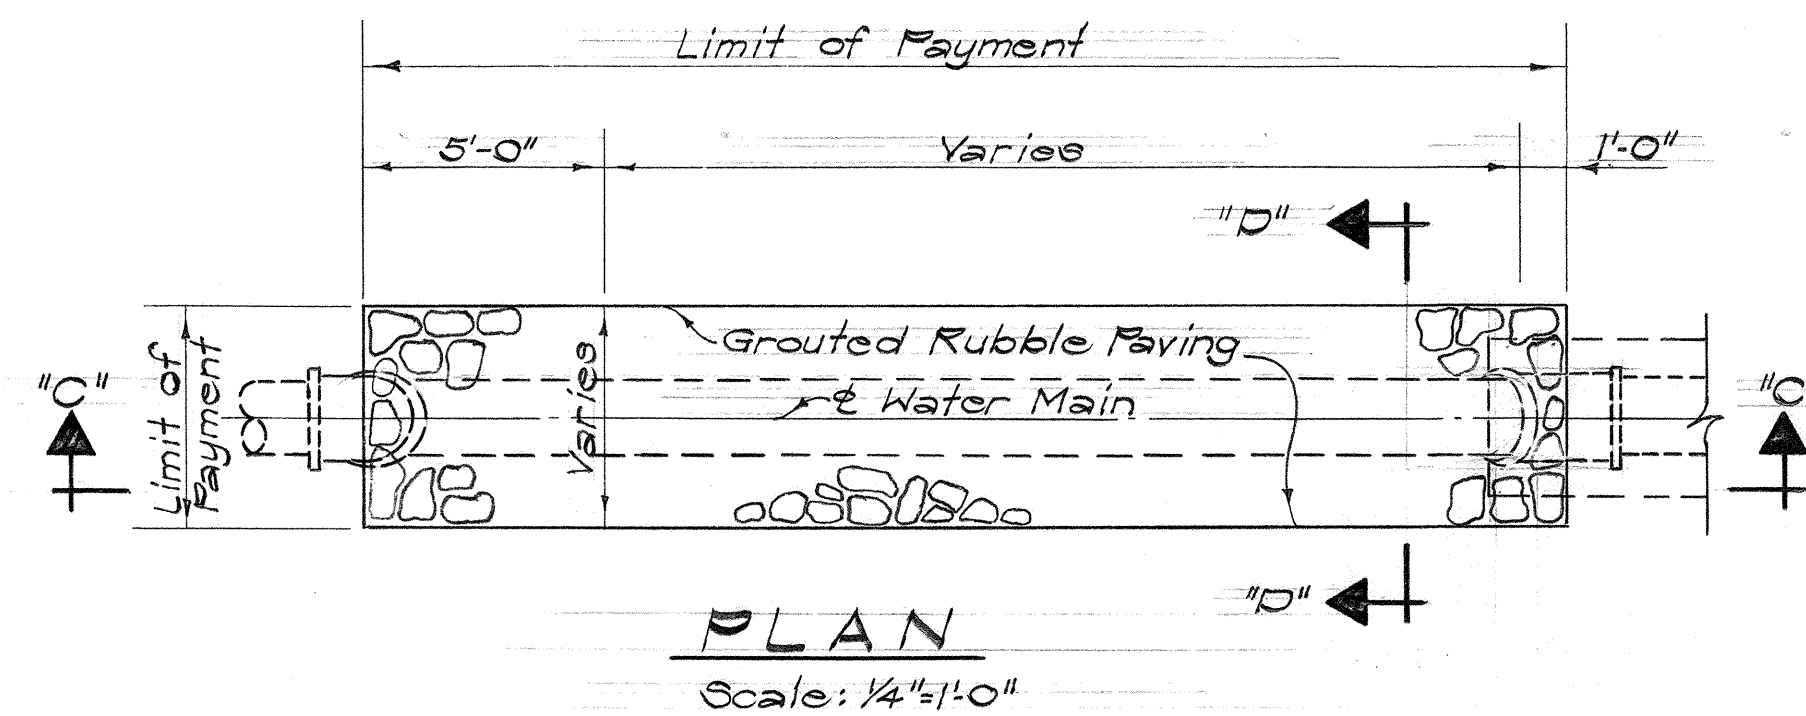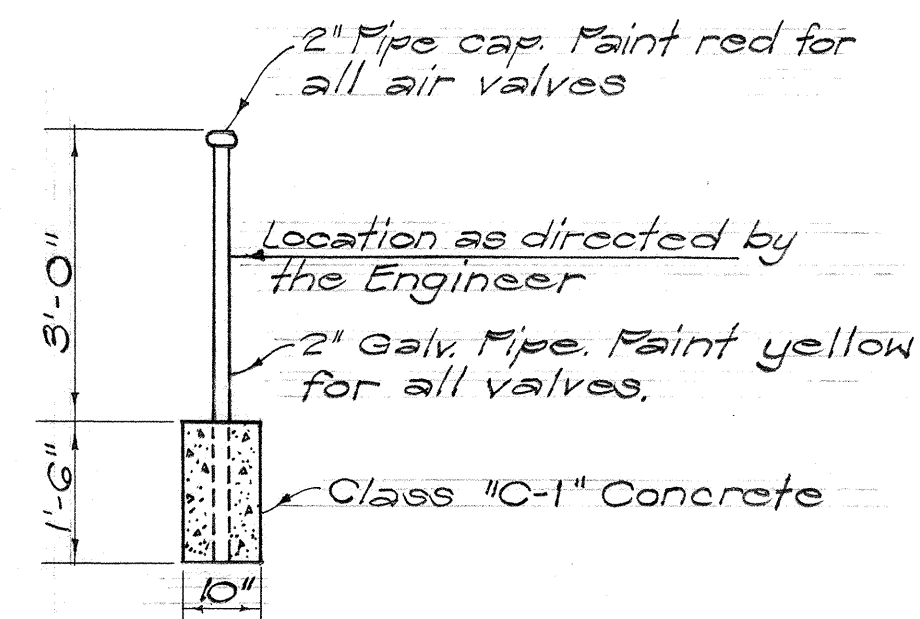

SECTION "E-E"

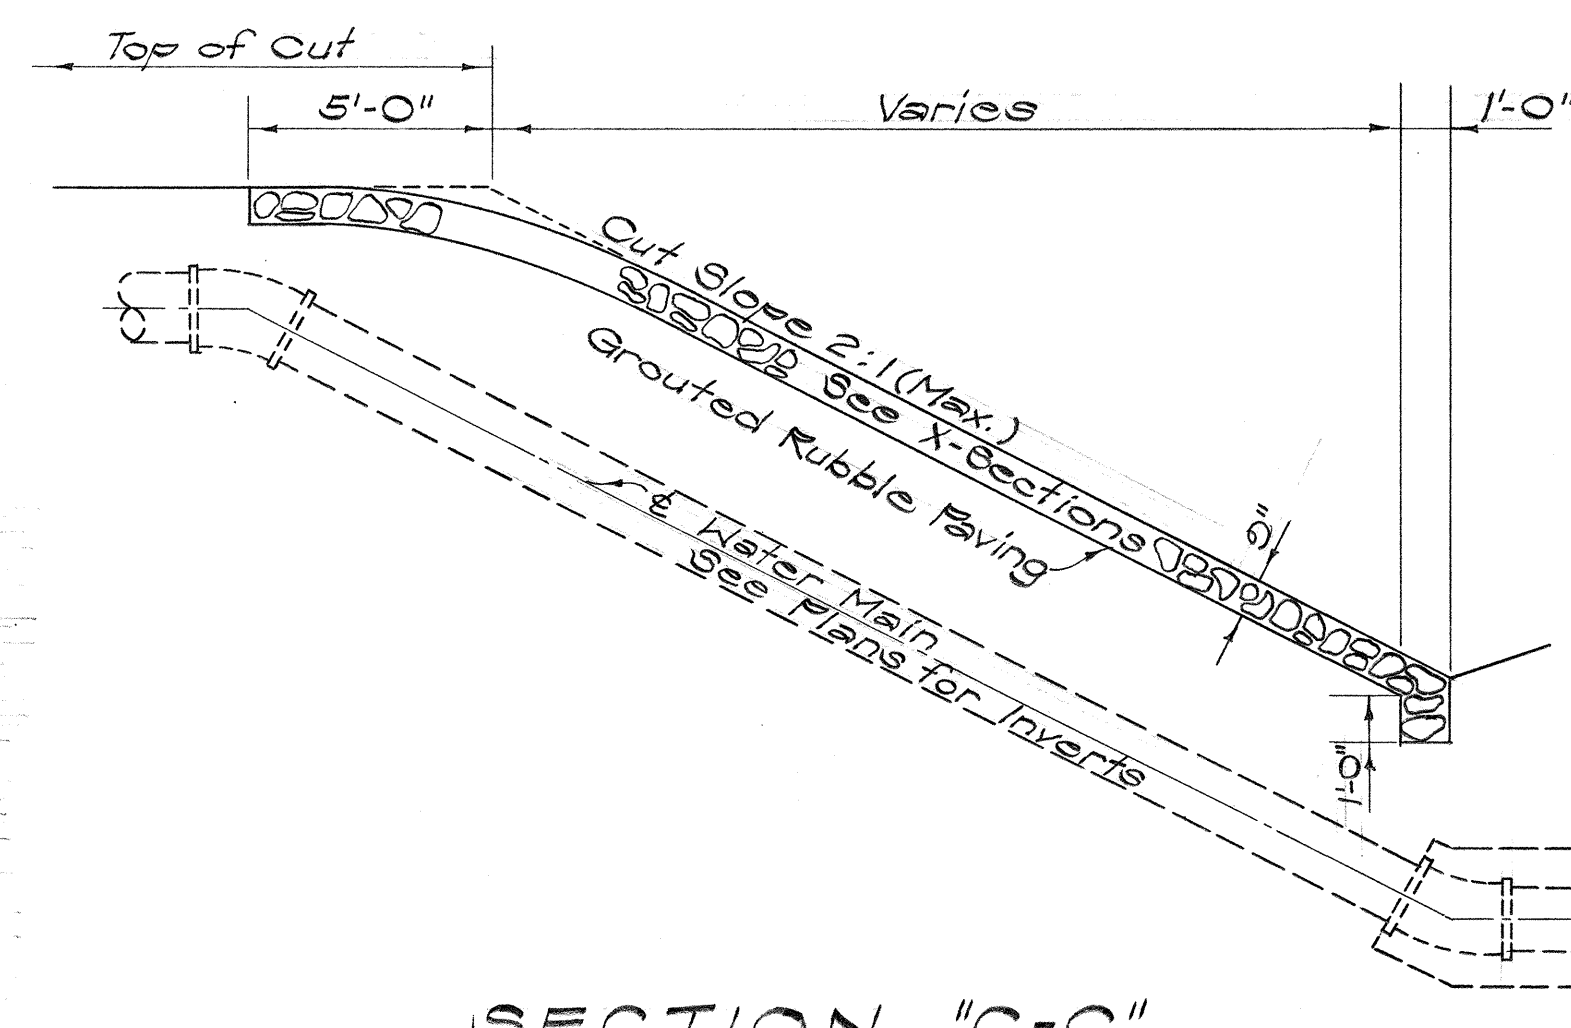


SECTION "C-C"
Scale: 1/4" = 1'-0"

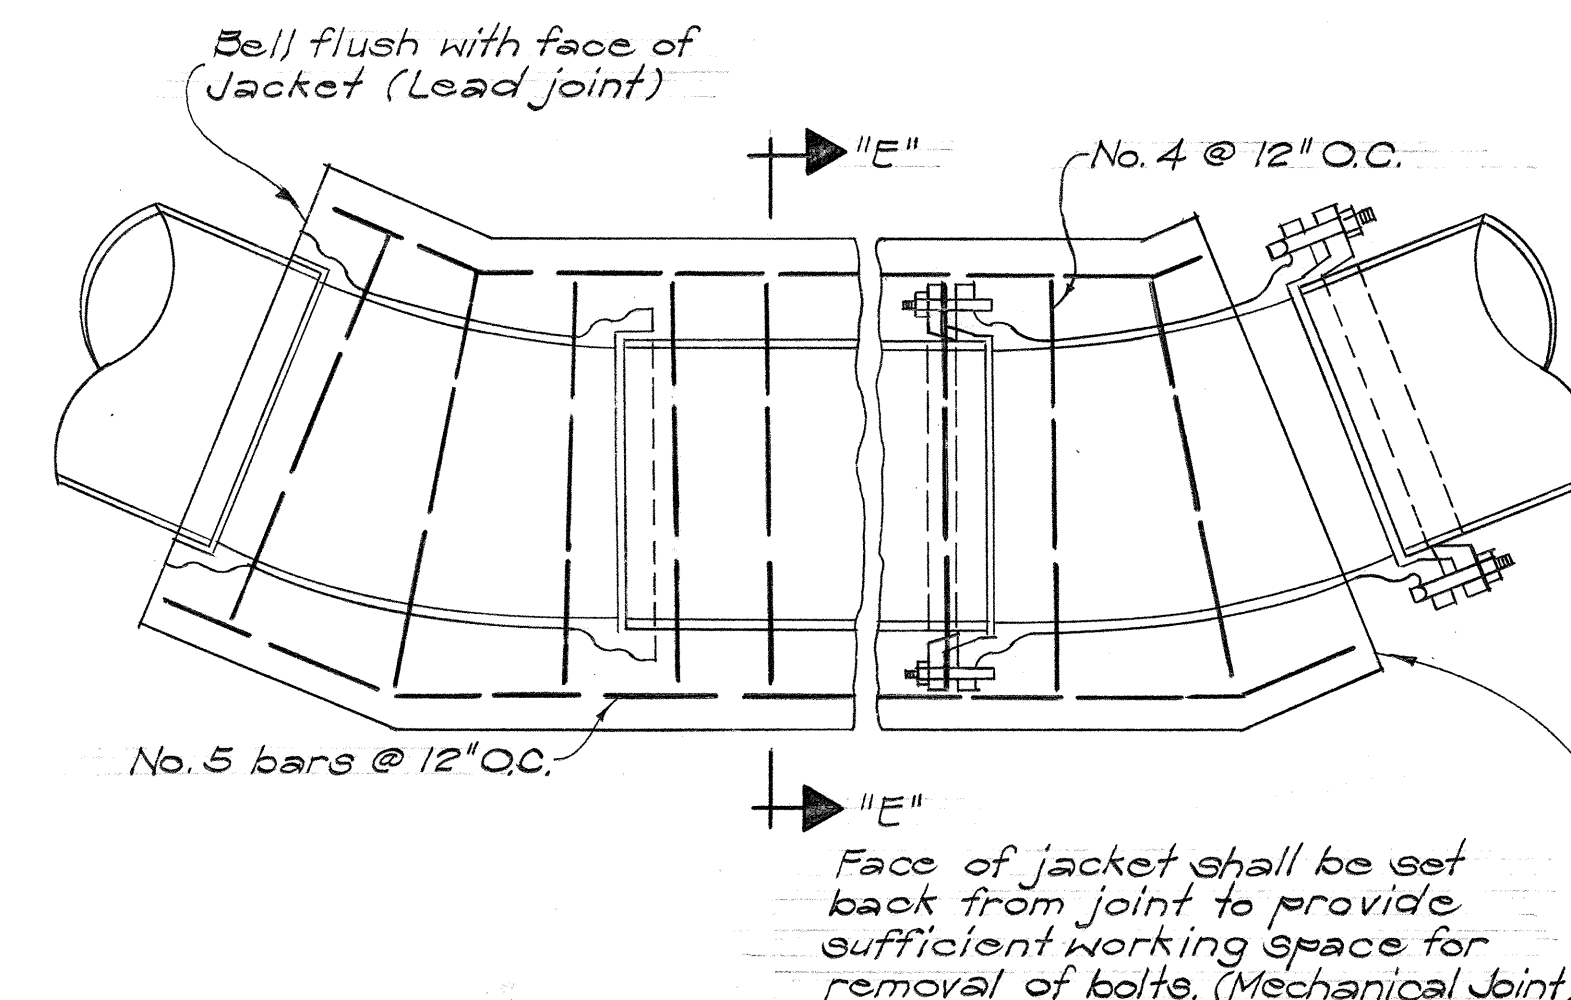


NOTE:
Jacket to be poured after completion of test. 2 1/2" depth of lead for lead joint pipe required at all embedded joints. Wherever construction joints are required 6" rubber or neoprene waterstops shall be installed.


REINFORCED CONCRETE JACKET
Not To Scale

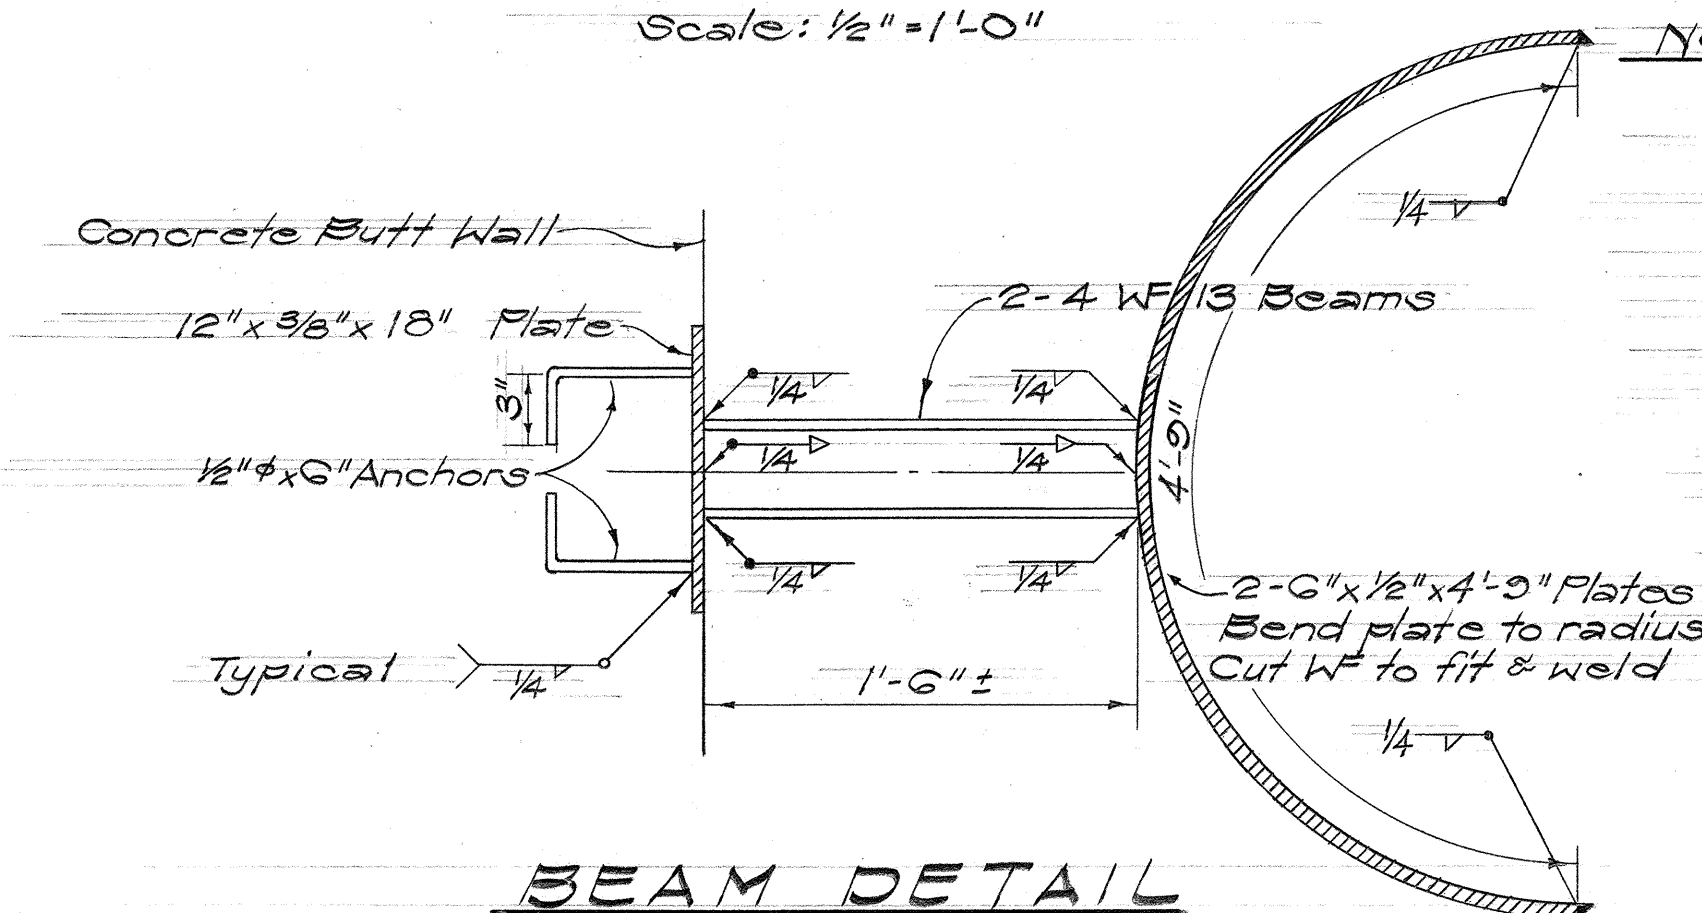

BEAM DETAIL
Scale: 1/2" = 1'-0"

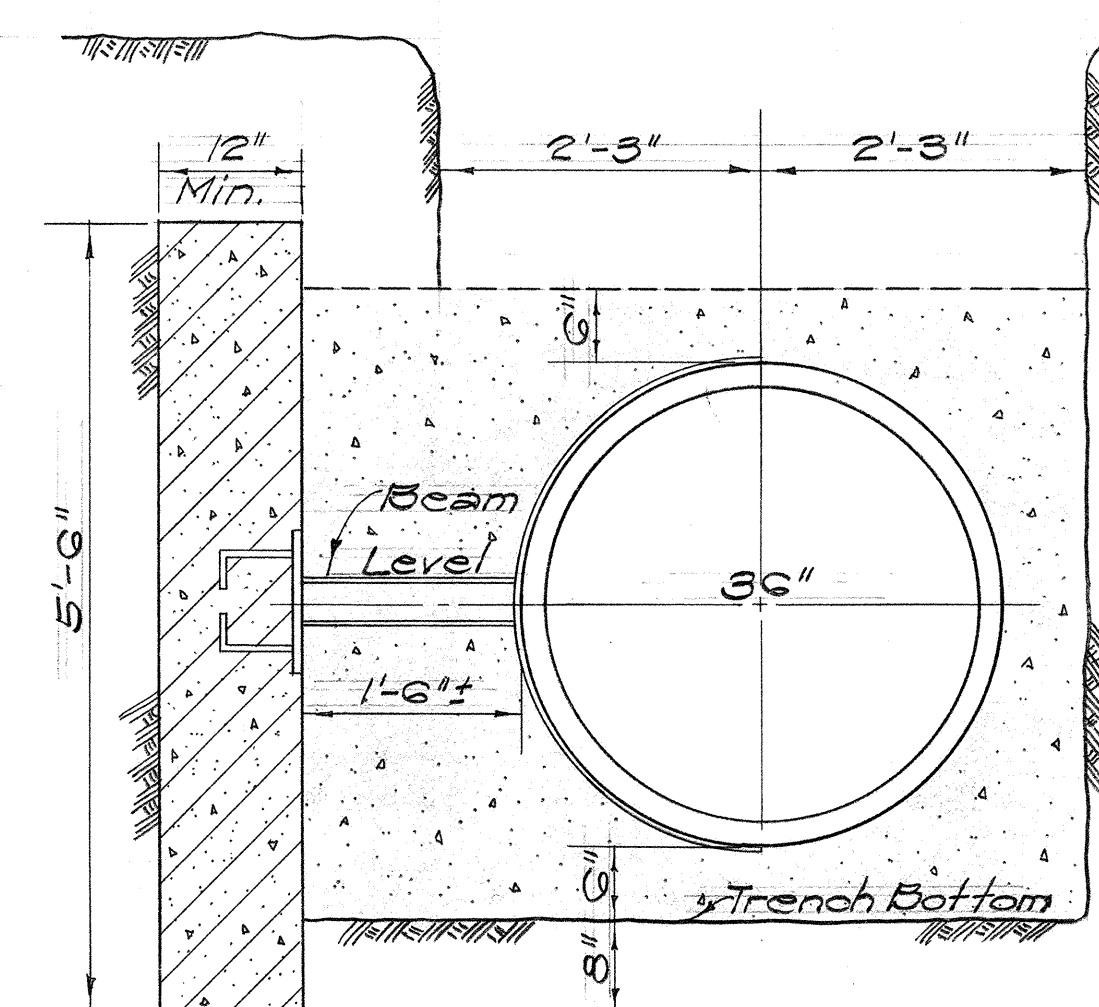


SECTION "A-A"
Scale: 3/4" = 1'-0"

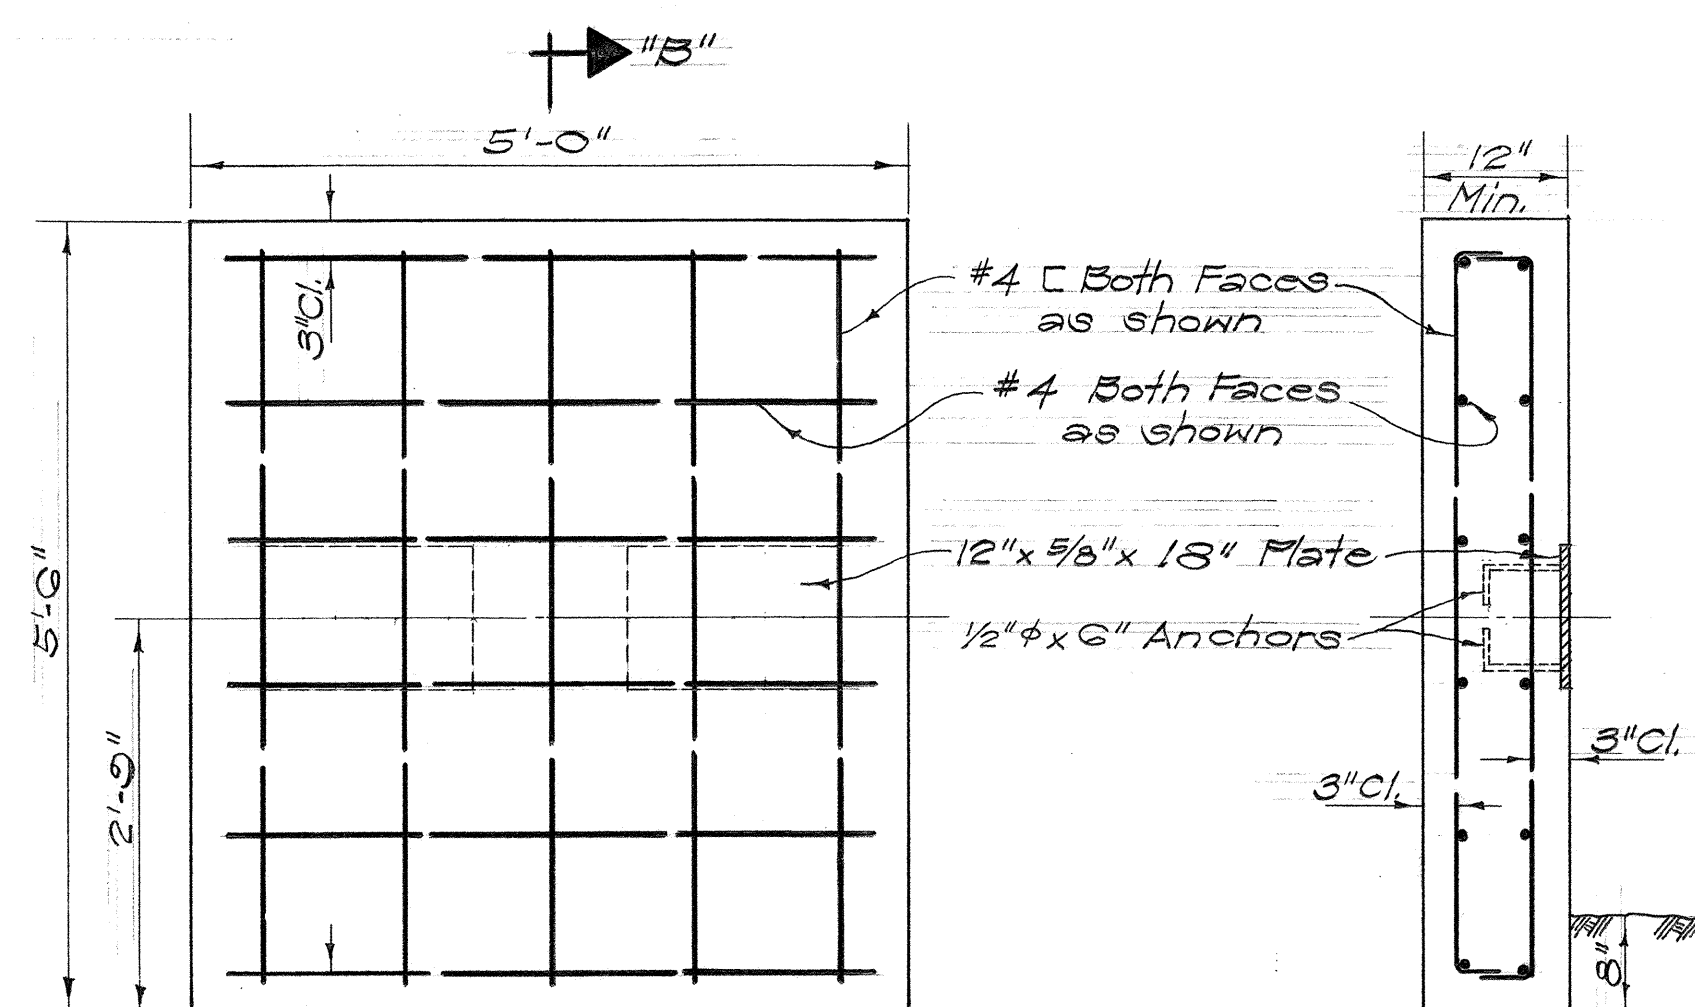

ELEVATION
CONCRETE BUTT WALL DETAIL
Scale: 3/4" = 1'-0"


DETAIL OF CONCRETE BLOCK
Scale: As Shown

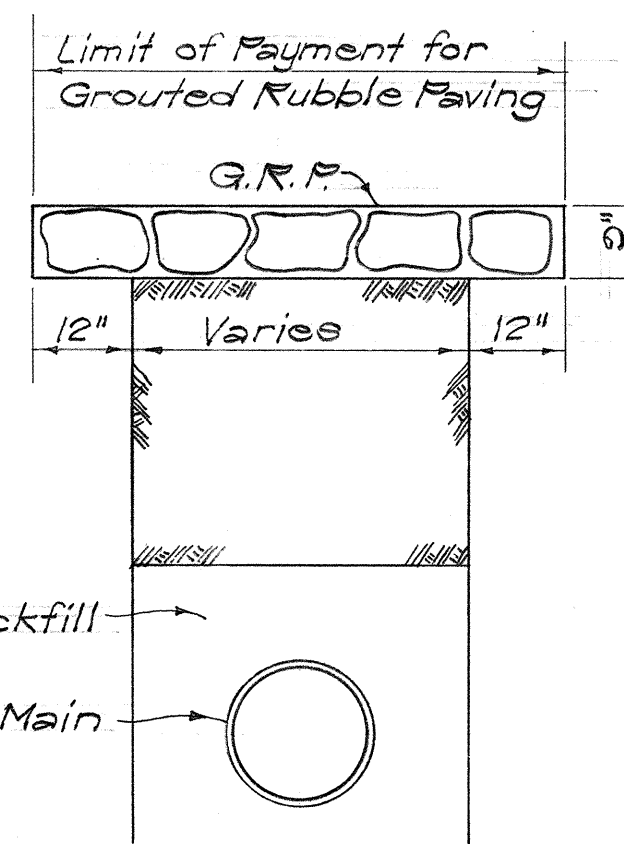

SECTION "D-D"
Scale: 1/2" = 1'-0"

NOTES:
1. G.R.P. required beyond the limit of payment shall be done at the Contractor's own expense.
2. Transverse slopes of G.R.P. to follow out slope.

TYPICAL DETAIL OF
GROUTED RUBBLE PAVING
SEAL OVER WATER MAIN
Scale: As Shown

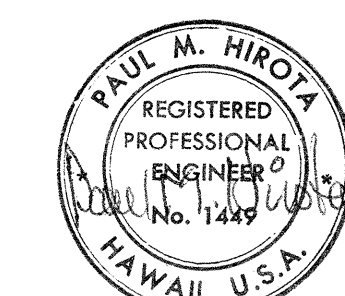

THIS WORK WAS PREPARED BY ME OR UNDER MY SUPERVISION.

APPROVED: *[Signature]* 8/1/68
Chief, Engineering Division Date
Board of Water Supply

STATE OF HAWAII
DEPARTMENT OF TRANSPORTATION
HIGHWAYS DIVISION


WATER DETAILS

INTERSTATE ROUTE H-1
PROJ. NO. I-H-1(16)11




Scale As Shown Date 8/10/68
SHEET No. 13 OF 27 SHEETS

FED. ROAD DIST. NO.	STATE	FED. AID PROJ. NO.	FISCAL YEAR	SHEET NO.	TOTAL SHEETS
HAWAII	HAW.	I-H-1(164)12 UNIT 2	1969	62	128
		I-H-1(16)11			

NOTE:
Typical Details of Reaction Block with Structural Strut. Details of Actual Block to be used shall be furnished during Construction.

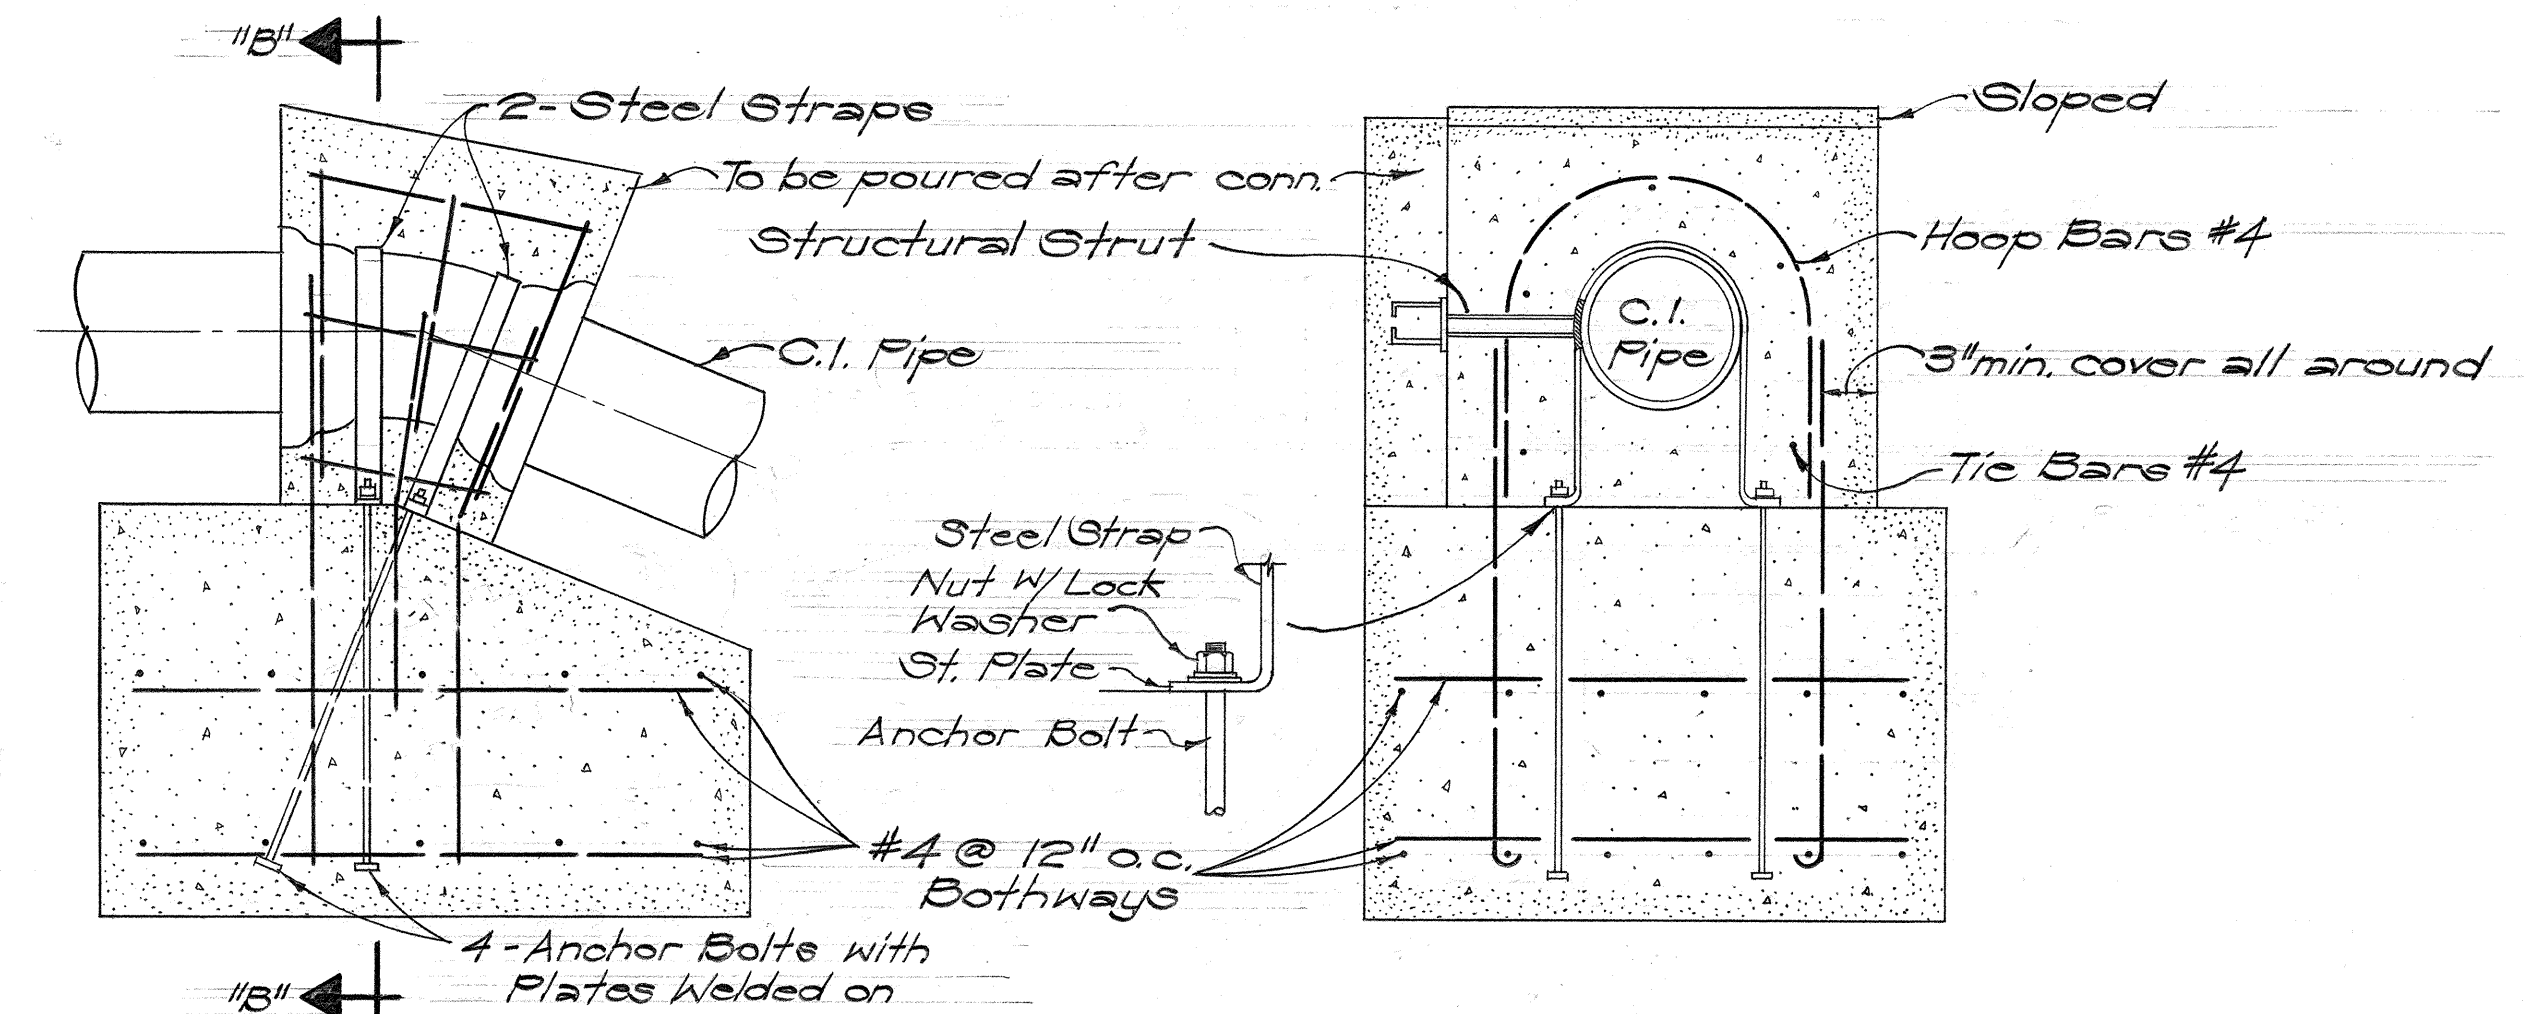

ELEVATION
REINFORCED REACTION BLOCK FOR TOP VERTICAL BENDS
Not to Scale

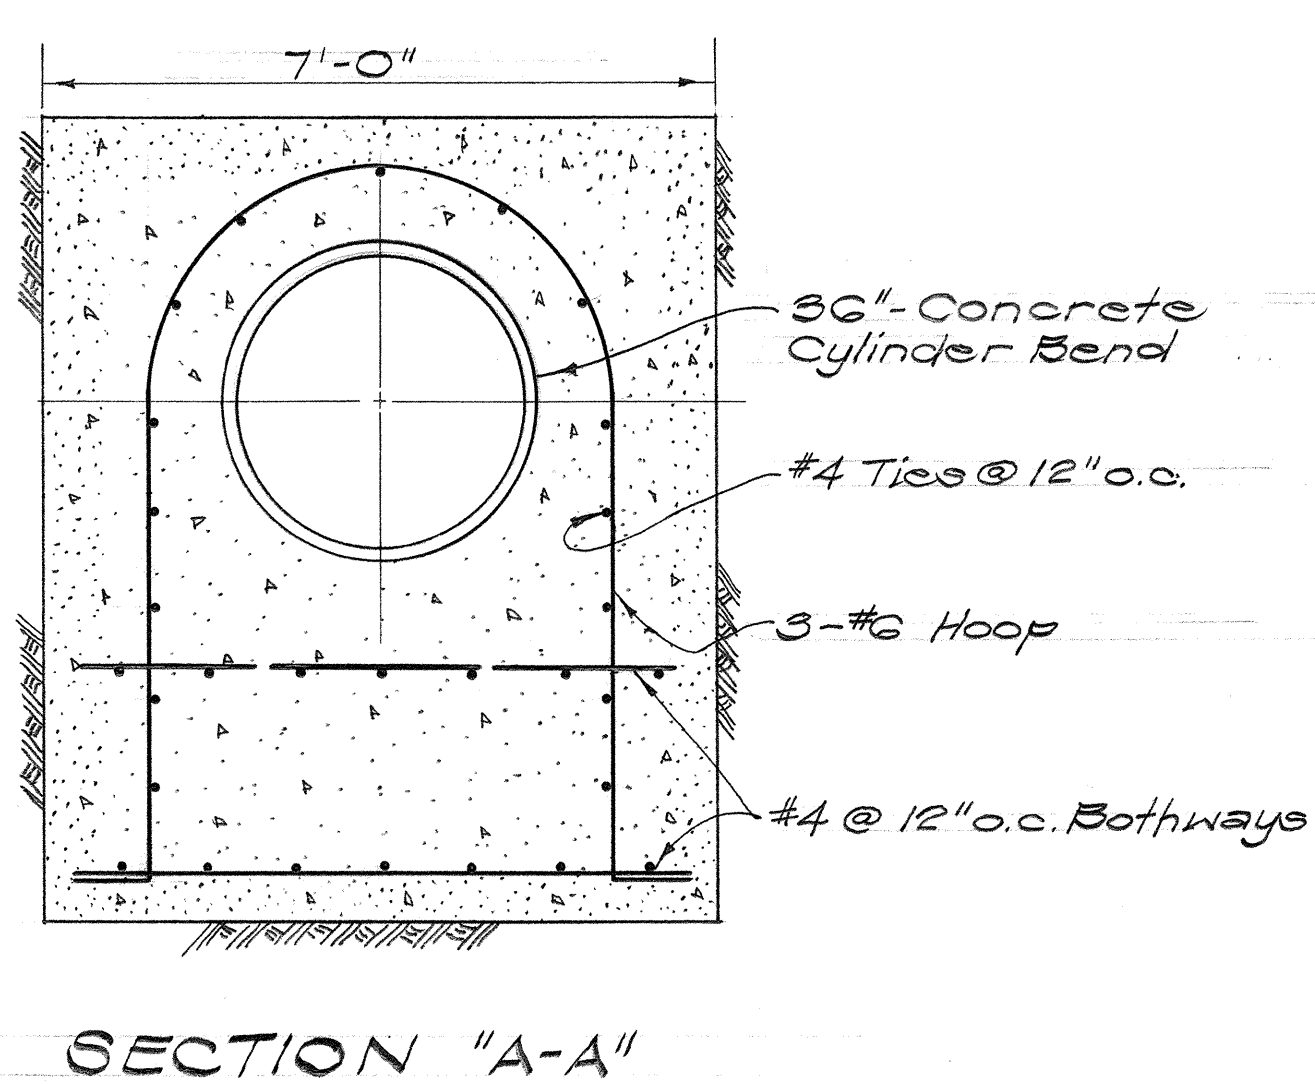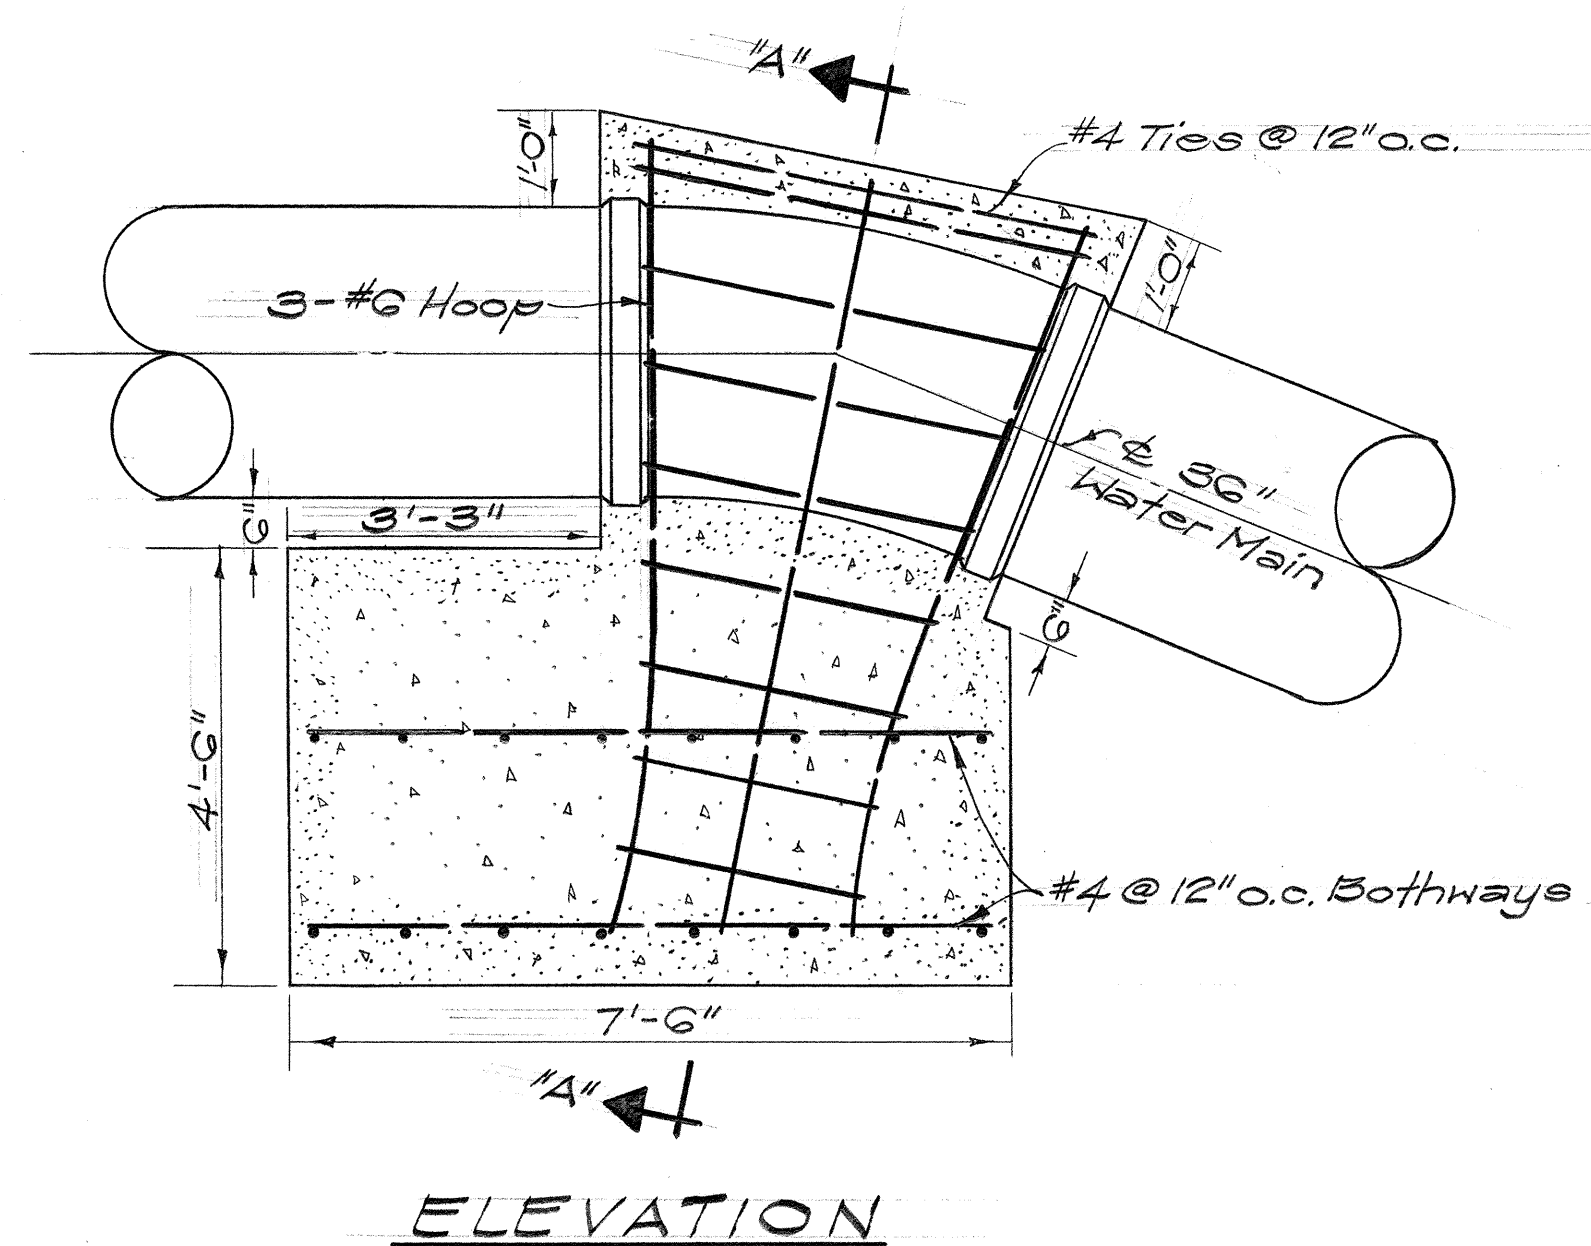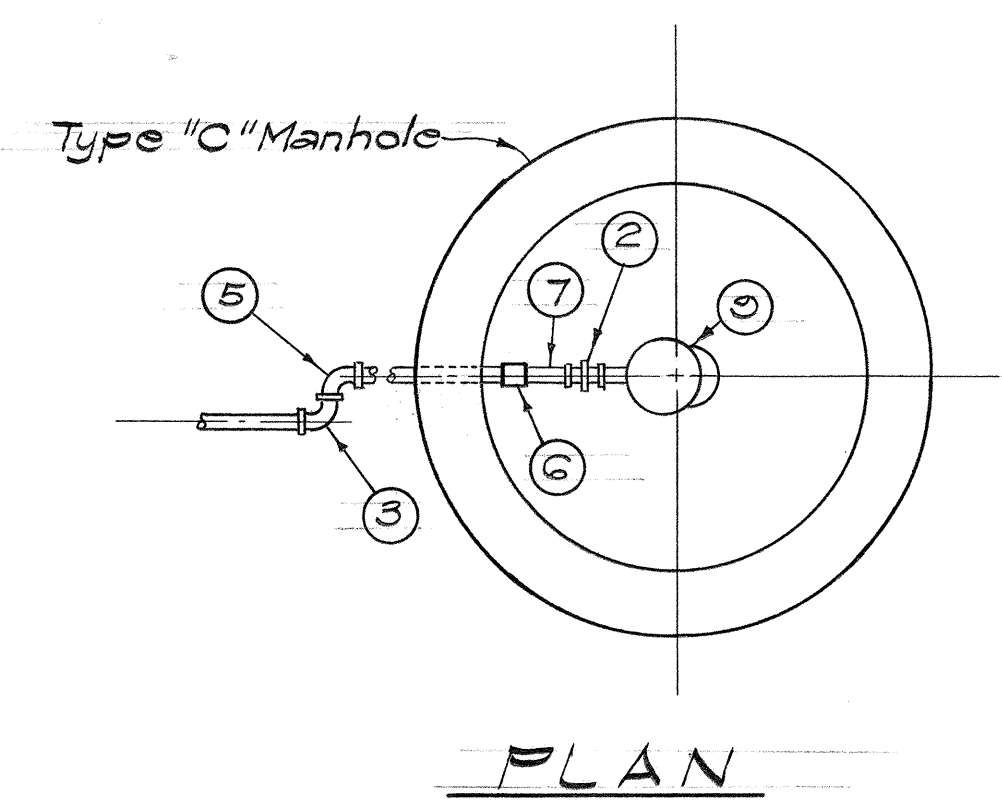


- 3" minimum cover for all reinforcing.
- Design pressure - 150 p.s.i.
- Approximately 14 c.y. Class "B" Concrete.
- Concrete block subject to field revision.

CONCRETE BLOCK
36" - TOP VERTICAL BEND
Scale: 1/2" = 1'-0"

LIST OF MATERIAL

ITEM	NO. REQ.	DESCRIPTION
1	1	1/2" x 2" Corporation Stop
2	2	2" Union, Bronze
3	3	2" 90° Elbow, Bronze
4	2	2" Copper Pipe, Cut to fit
5	2	2" Street Elbow, Bronze
6	1	2" Stop Cork
7	2	2" Dia. x 3" Nipple, Brass
8	1	2" Dia. x 4" Nipple, Brass
9	1	2" Air Valve
10	2	Brick Support

DETAIL OF CONNECTION FOR AIR ELIMINATING VALVE
Scale: 1/2" = 1'-0"

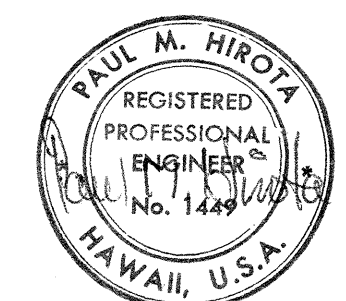

THIS WORK WAS PREPARED BY ME OR UNDER MY SUPERVISION.


APPROVED: *[Signature]* 8/4/68
Chief, Engineering Division
Board of Water Supply

STATE OF HAWAII
DEPARTMENT OF TRANSPORTATION
HIGHWAYS DIVISION

WATER DETAILS


INTERSTATE ROUTE H-1
PROJ. NO. I-H-1(16)11
Scale: As Shown Date: 8/19/68
SHEET No. 14 OF 27 SHEETS

FED. ROAD DIST. NO.	STATE	FED. AID PROJ. NO.	FISCAL YEAR	SHEET NO.	TOTAL SHEETS
HAWAII	HAW.	I-H-1(16):12 UNIT 2	1969	63	128
		I-H-1(16):11			

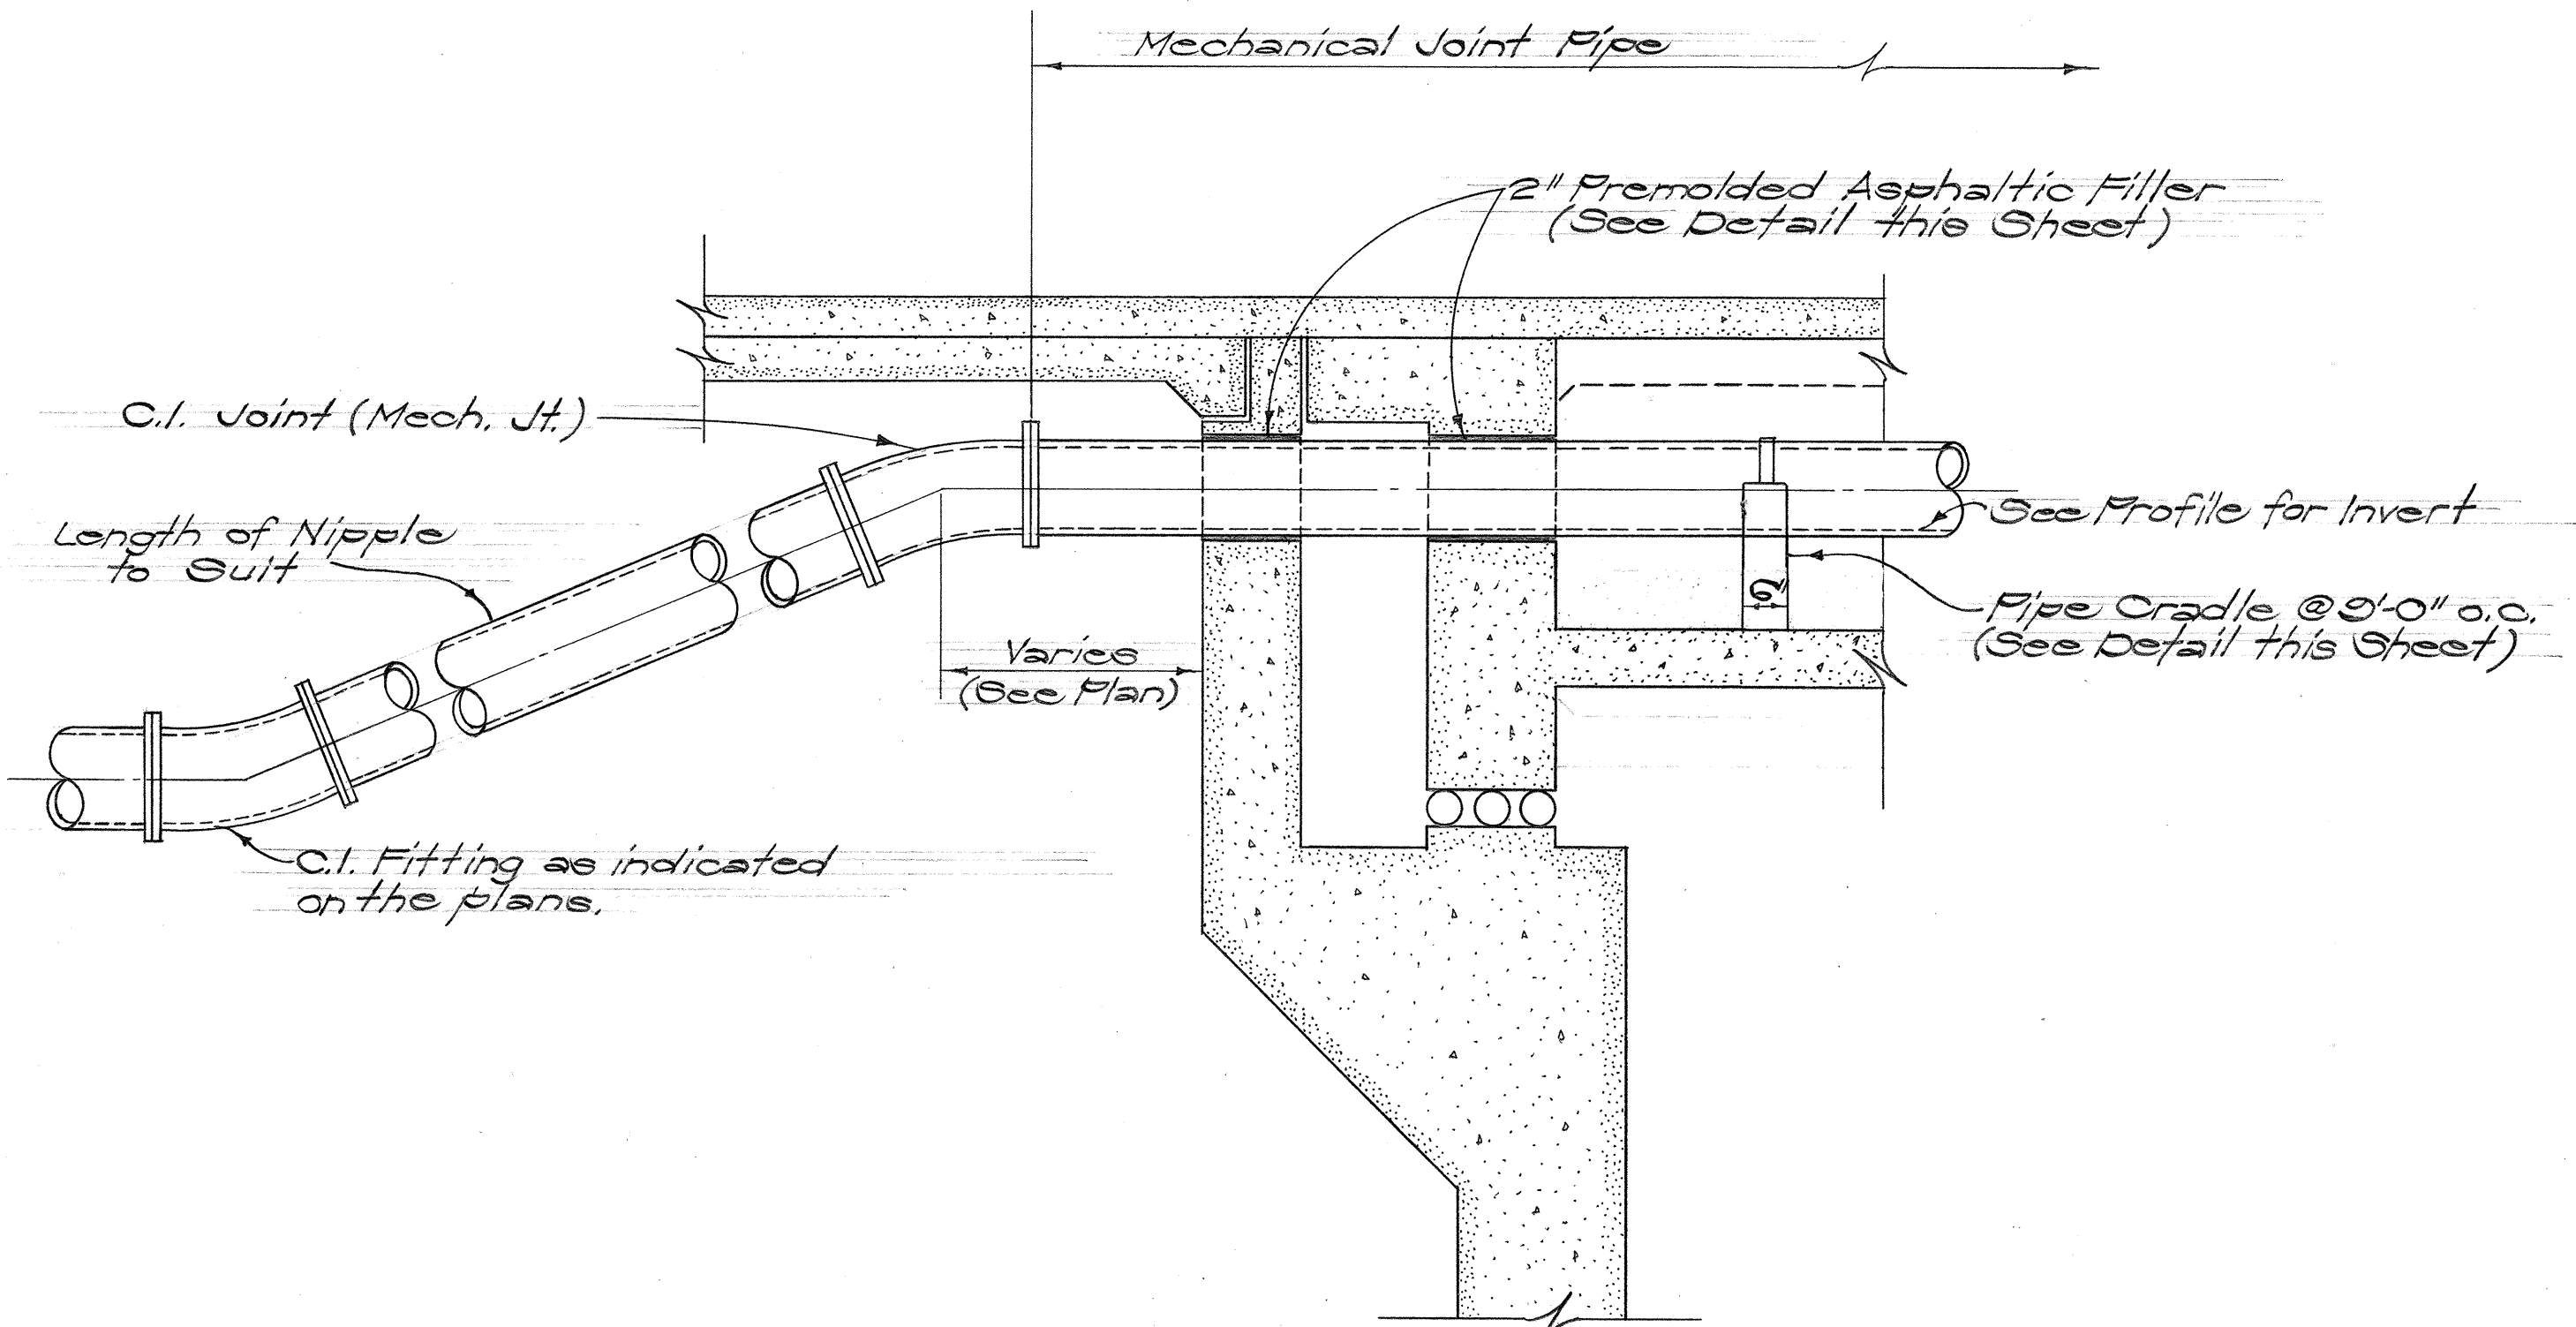


TYPICAL SECTION OF WATER MAIN @ ABUTMENT
Scale: 1/2" = 1'-0"


NOTE:
All exposed metal surfaces shall be given one shop coat of approved primer and final coat of rust preventive (metal gray) paint approved by the Engineer.

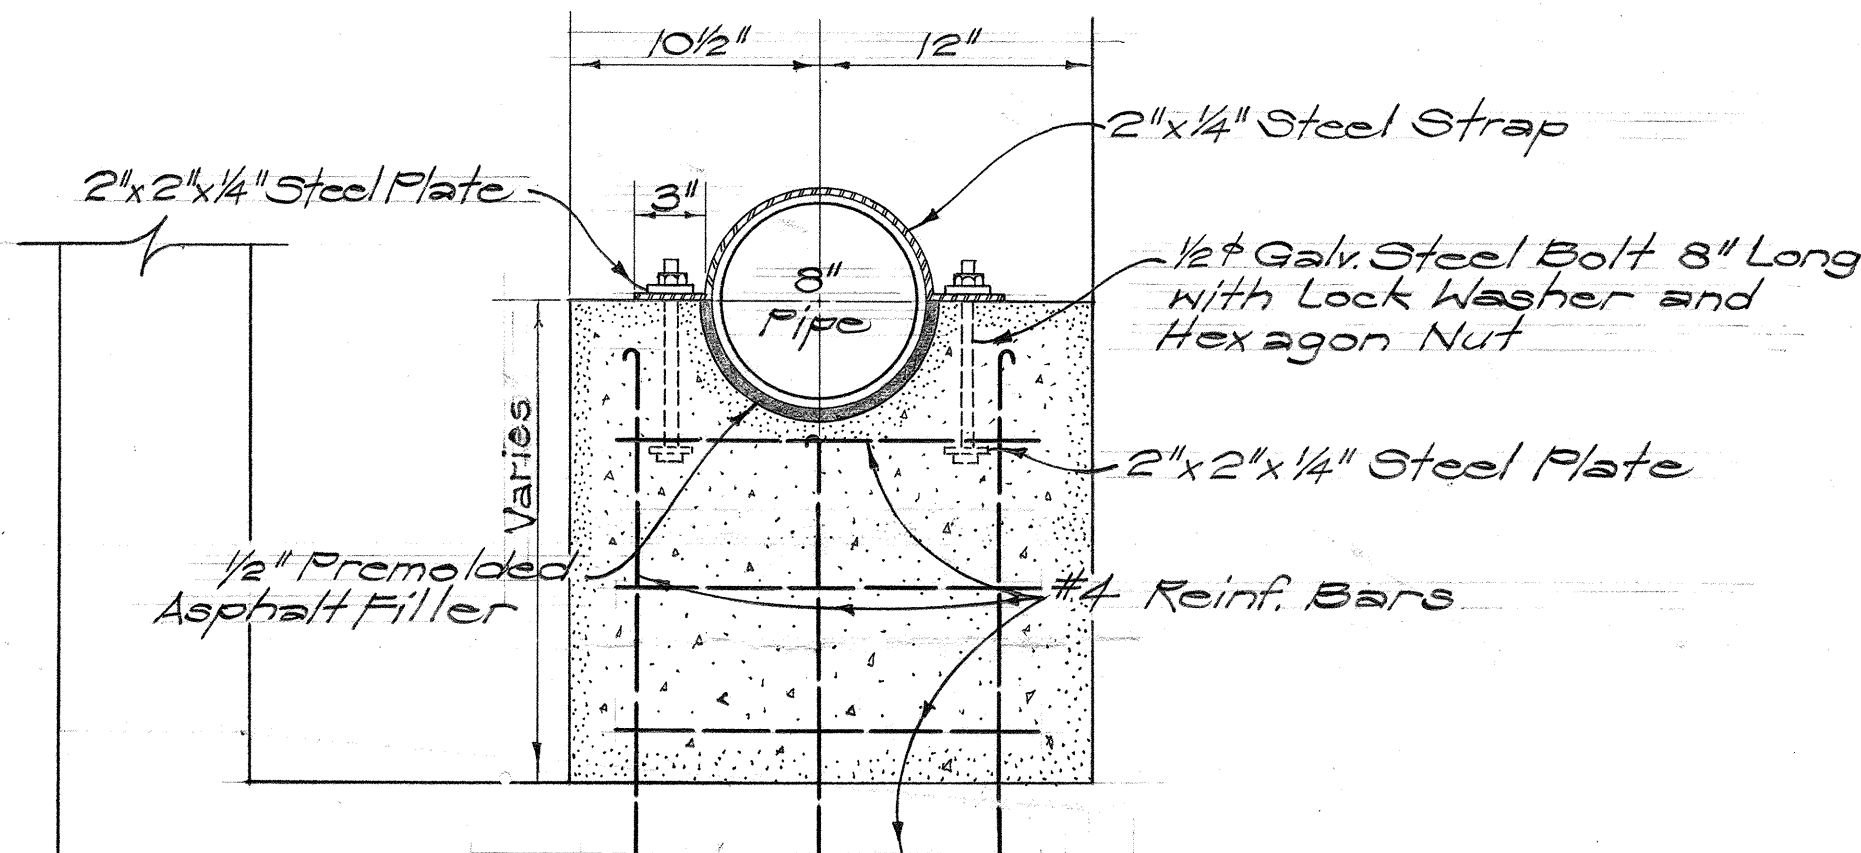


DETAIL OF PIPE CRADLE W/ STRAP
Scale: 1/2" = 1'-0"

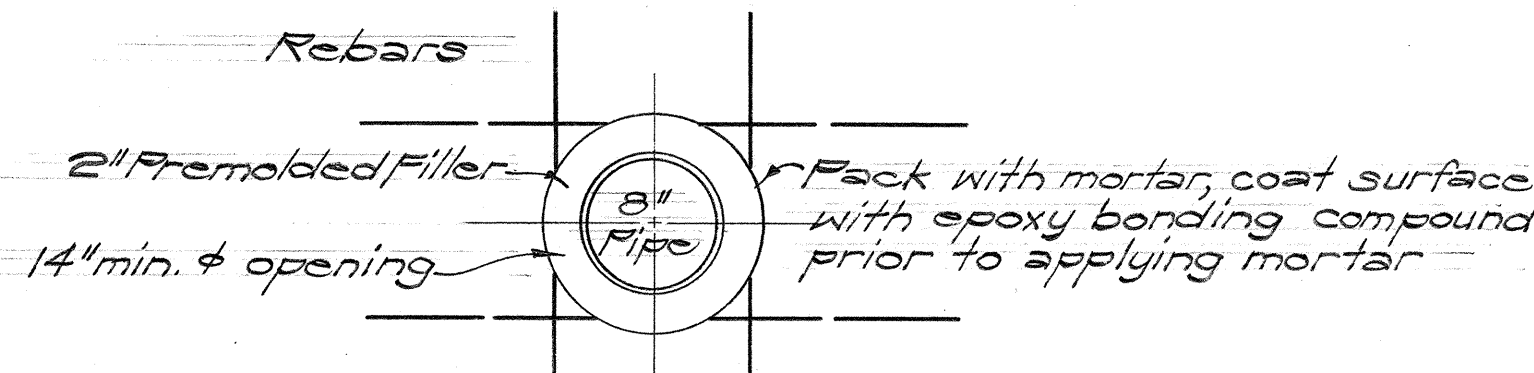

DETAIL OF PIPE THRU ABUTMENT
Scale: 1" = 1'-0"

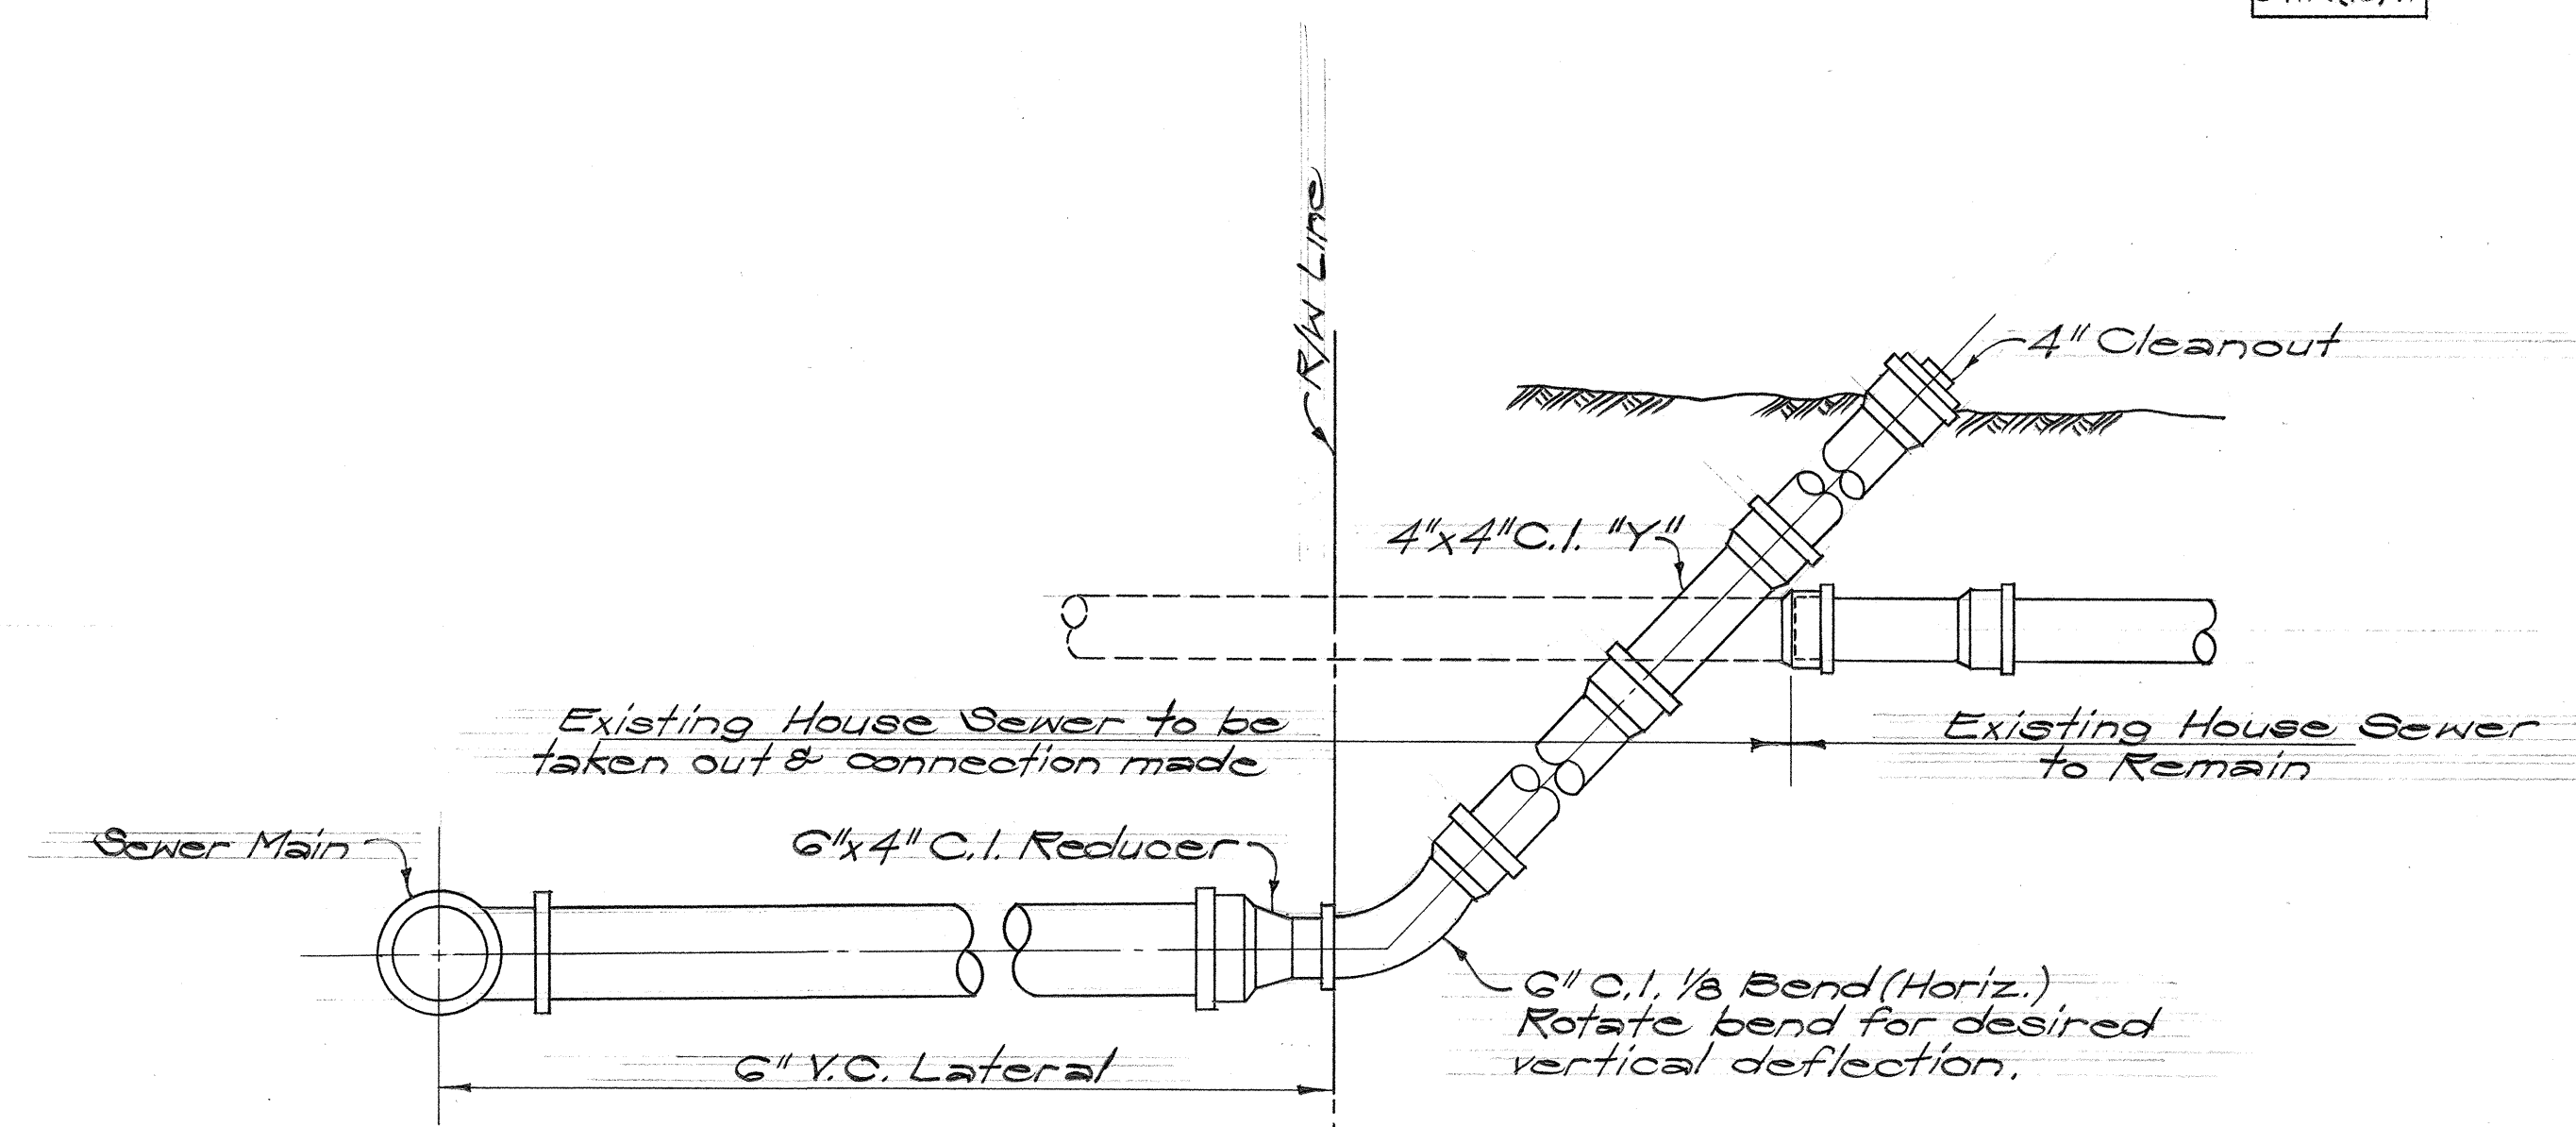

TYPICAL HOUSE SEWER CONNECTION DETAIL
Not to Scale

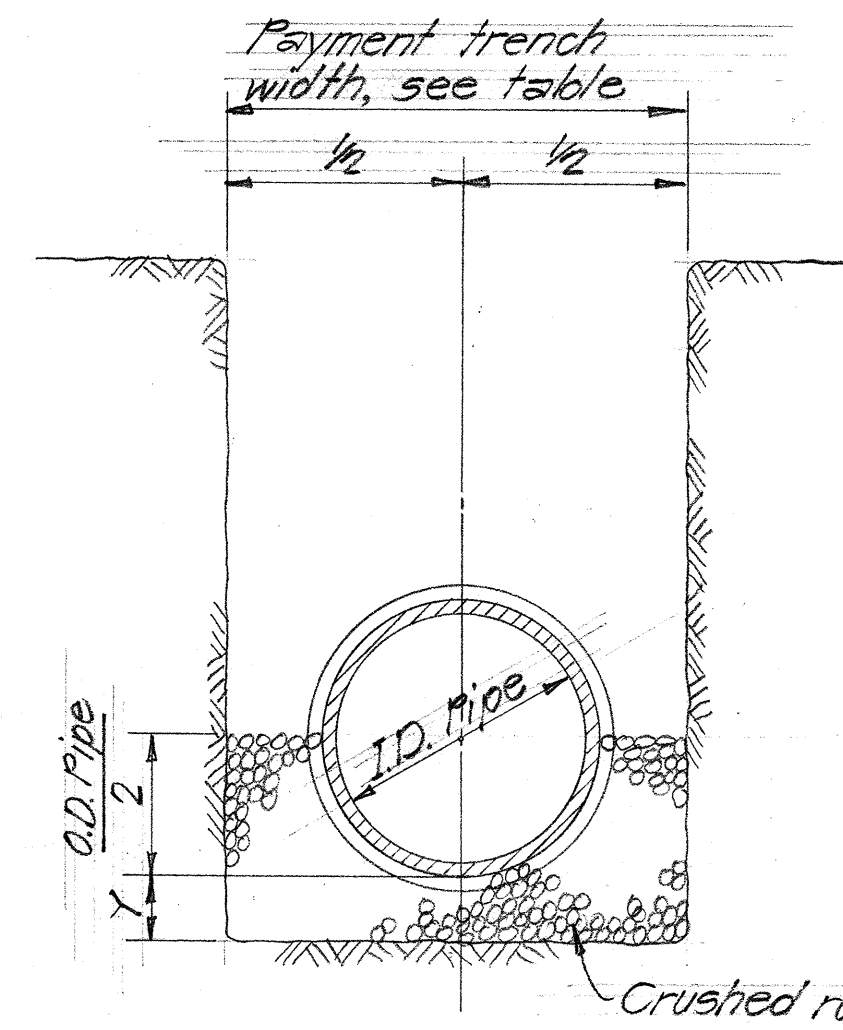

PIPE SIZE	PAYMENT TRENCH WIDTH	CRUSHED ROCK CRADLE "Y" (MIN.)	CY/LF
6"	24"	4"	.042
8"	24"	4"	.045
10"	24"	4"	.047
12"	30"	5"	.073
15"	36"	6"	.114
18"	41"	6"	.130
21"	45"	7"	.163
24"	50"	8"	.204
27"	53"	9"	.238
30"	57"	10"	.280

NOTE: Payment width of cradle shall be payment trench width.

ROCK CRADLE FOR VITRIFIED CLAY PIPE
N.T.S.



THIS WORK WAS PREPARED BY ME OR UNDER MY SUPERVISION.

APPROVED: *[Signature]* 8/10/68
for Sewer System Director, Division of Sewers

APPROVED: *[Signature]* 8/1/68
Chief, Engineering Division, Board of Water Supply

STATE OF HAWAII
DEPARTMENT OF TRANSPORTATION
HIGHWAYS DIVISION

SEWER & WATER DETAILS


INTERSTATE ROUTE H-1
PROJ. NO. I-H-1(16):11

Scale: As Shown Date: 8/16/68
SHEET No. 15 OF 27 SHEETS


FED. ROAD DIST. NO.	STATE	FED. AID PROJ. NO.	FISCAL YEAR	SHEET NO.	TOTAL SHEETS
HAWAII	HAWAII	HI-1(64)12, UNIT 2	1969	64	128
		HI-1(66)11			

NOTE:


Reinforced concrete manhole walls (See detail of plain manhole) shall be used for portions below the water table.

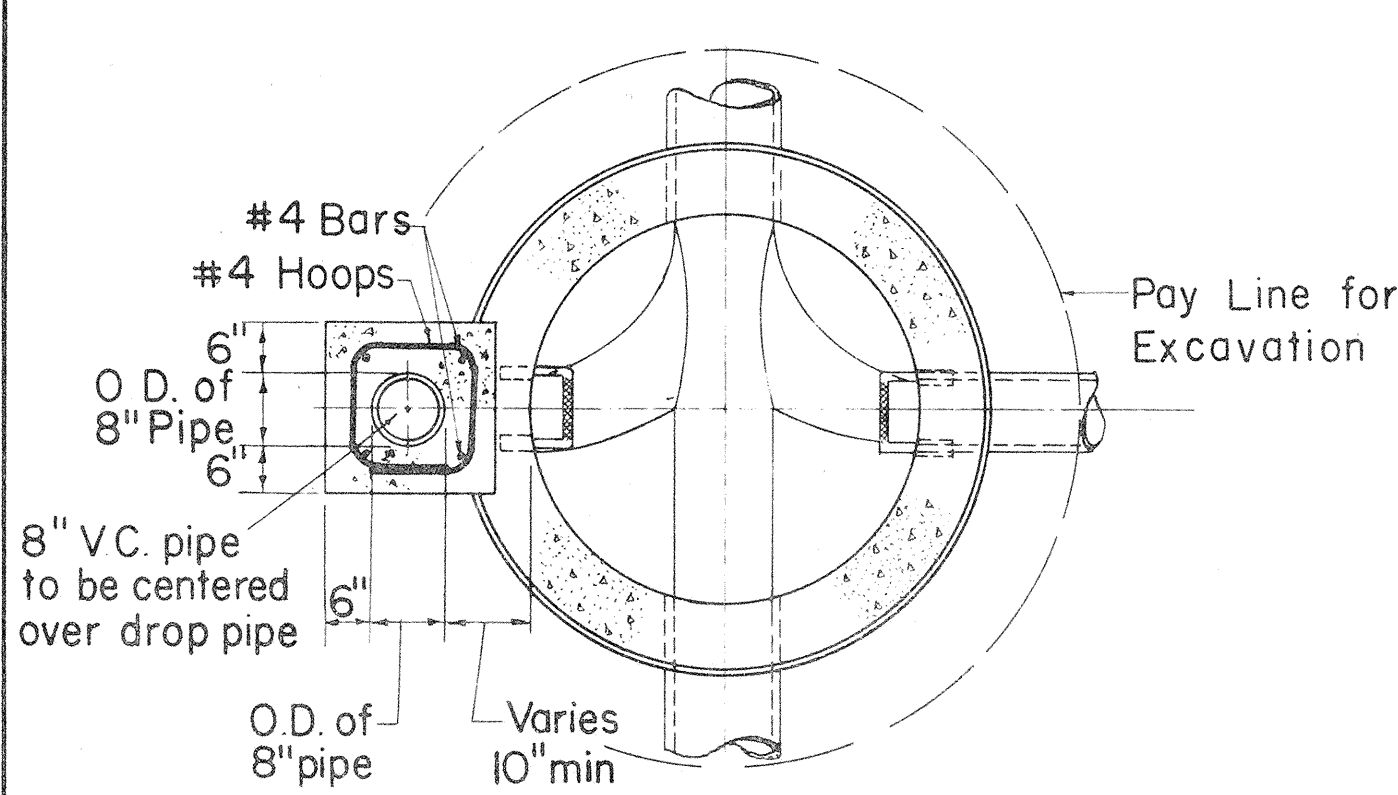


SECTION A-A
Scale: 1/2" = 1'-0"

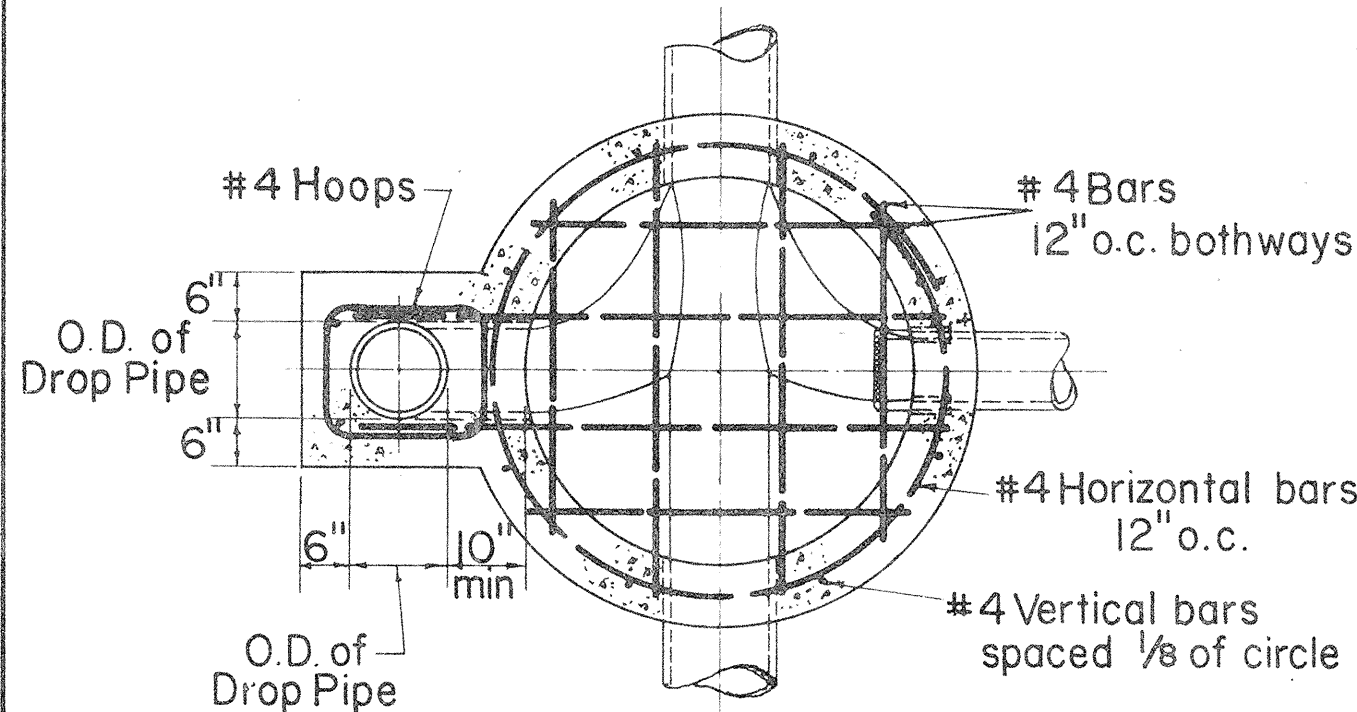


SECTION B-B
Scale: 1/2" = 1'-0"

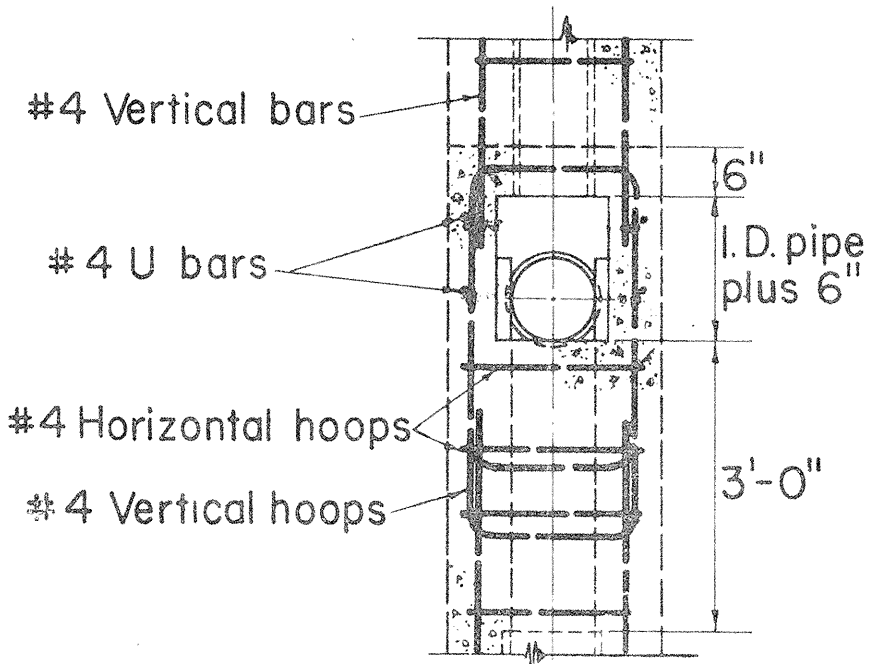


SECTION C-C
Scale: 1/2" = 1'-0"

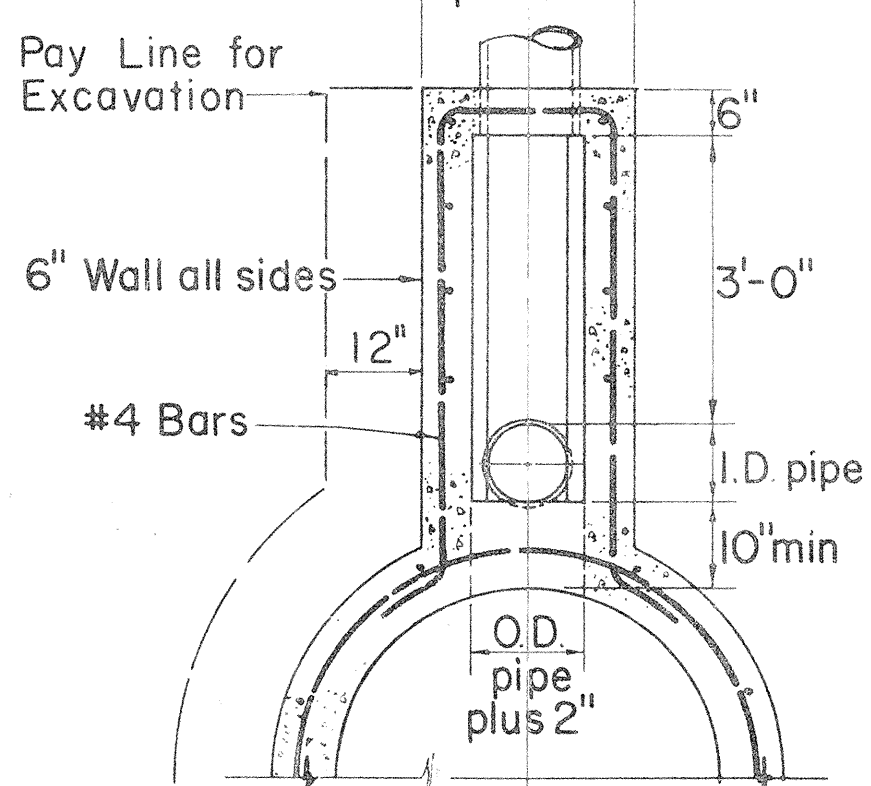


SECTION D-D
Scale: 1/2" = 1'-0"

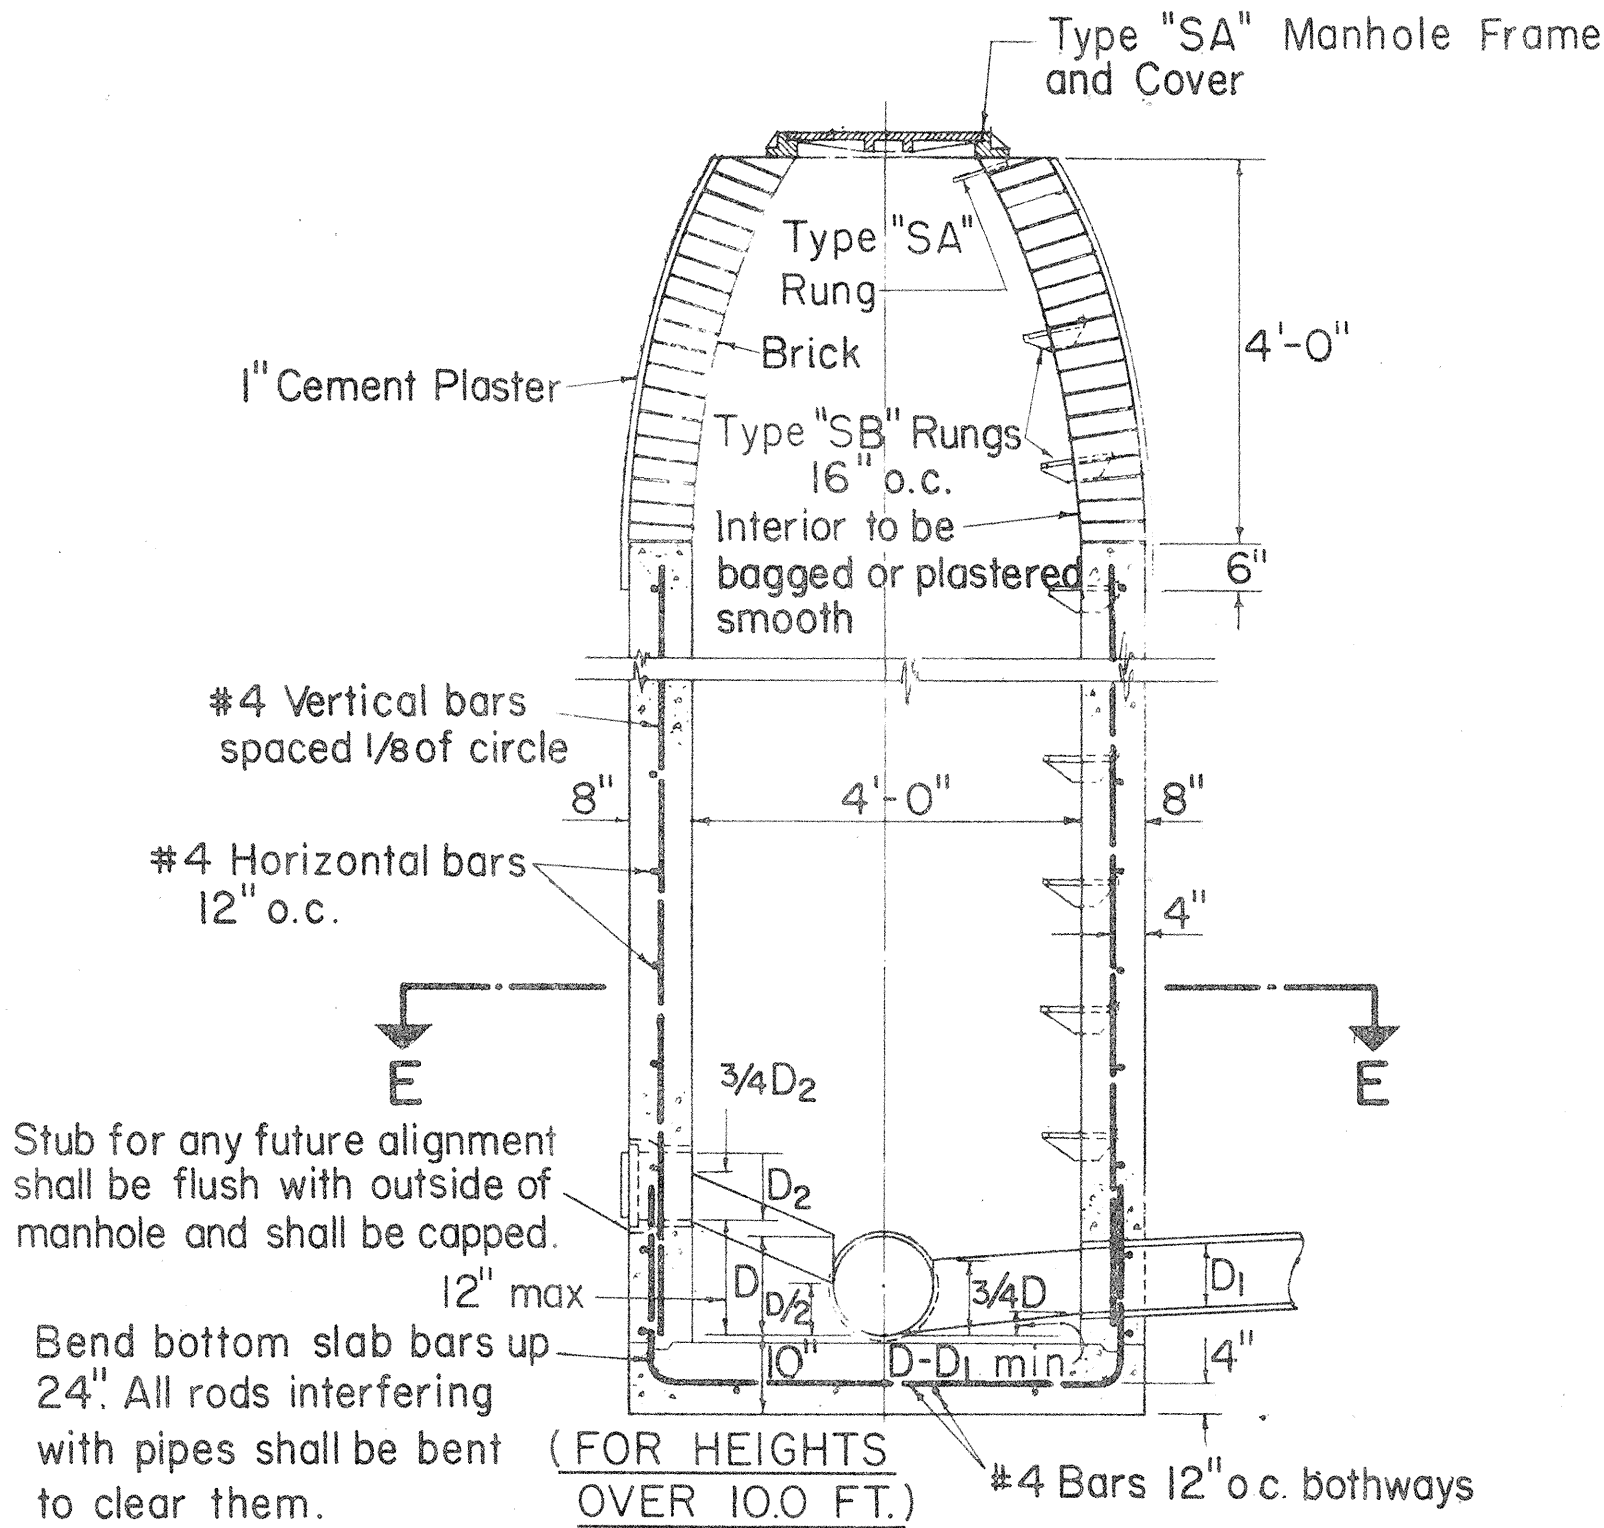


PLAIN MANHOLE
Scale: 1/2" = 1'-0"

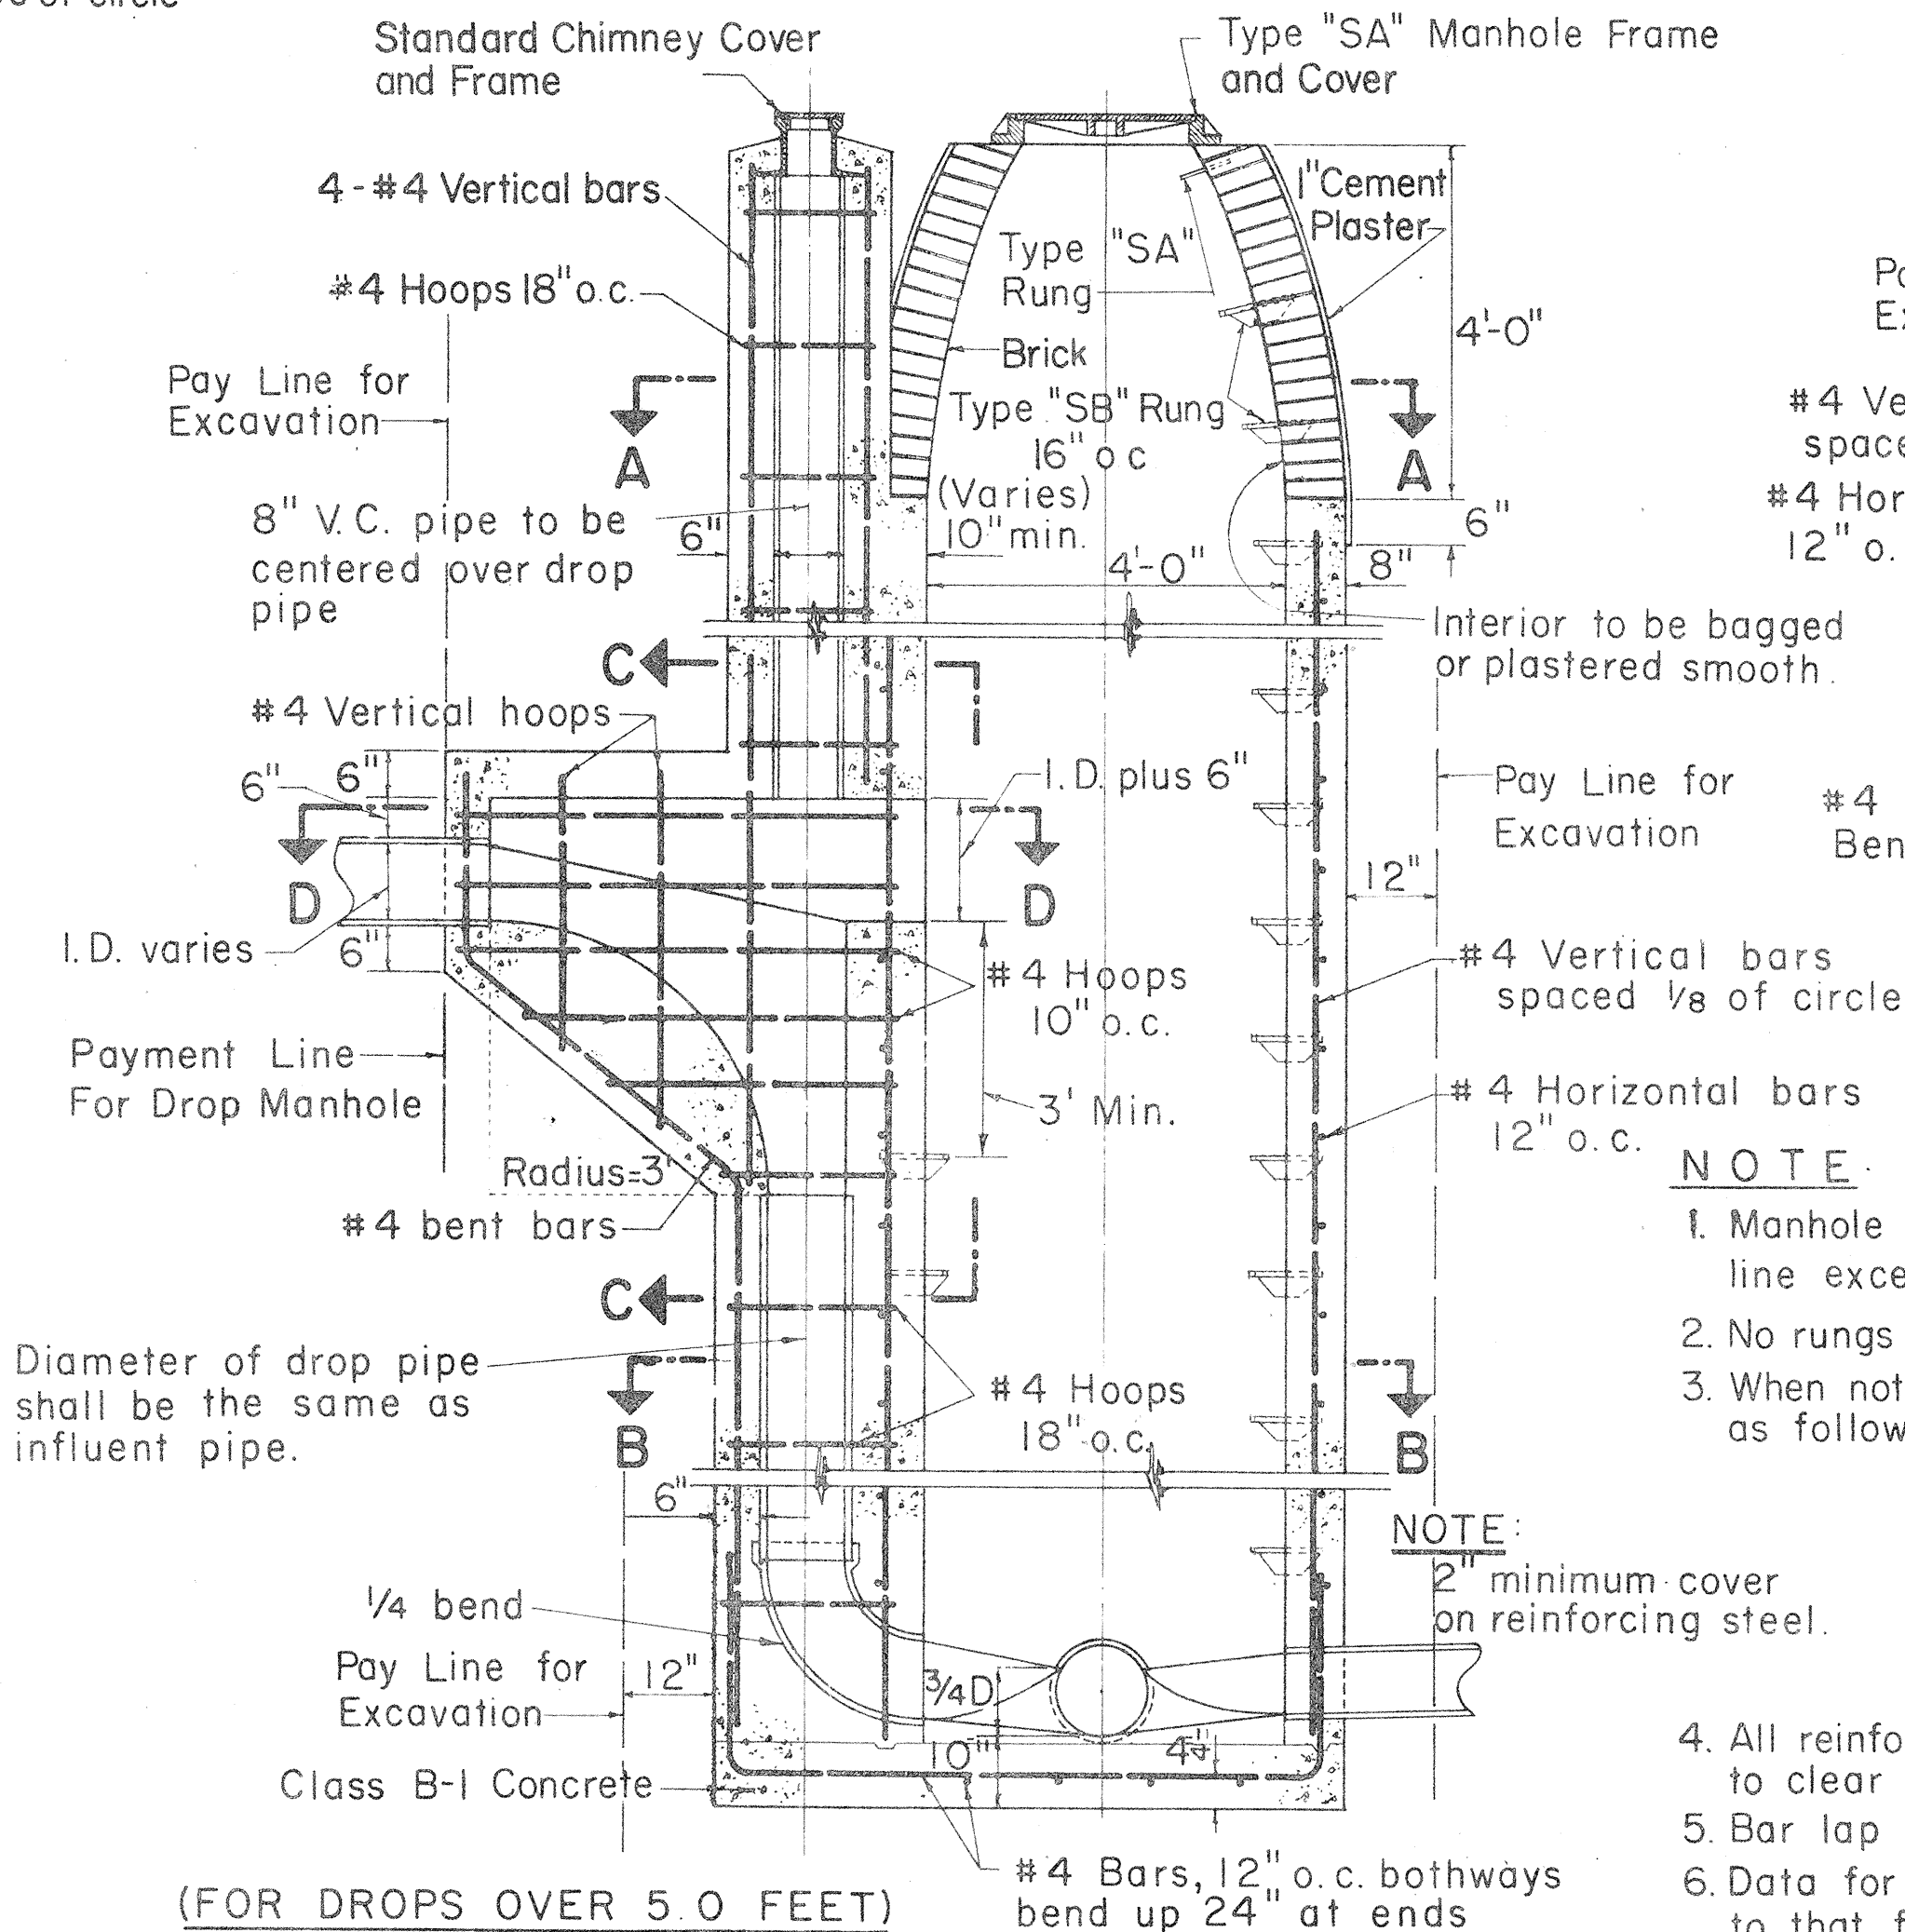

DROP MANHOLE
Scale: 1/2" = 1'-0"

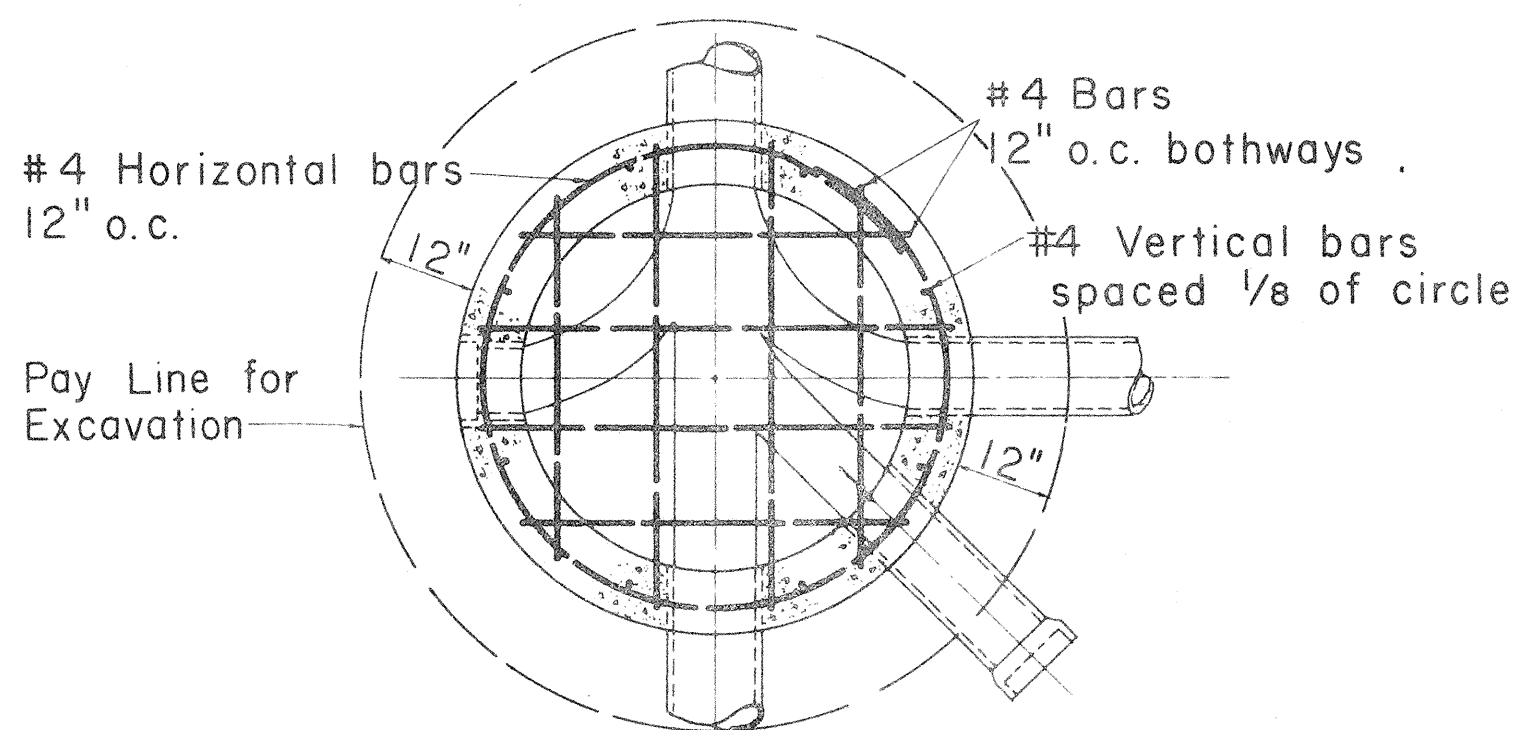

SECTION E-E
Scale: 1/2" = 1'-0"

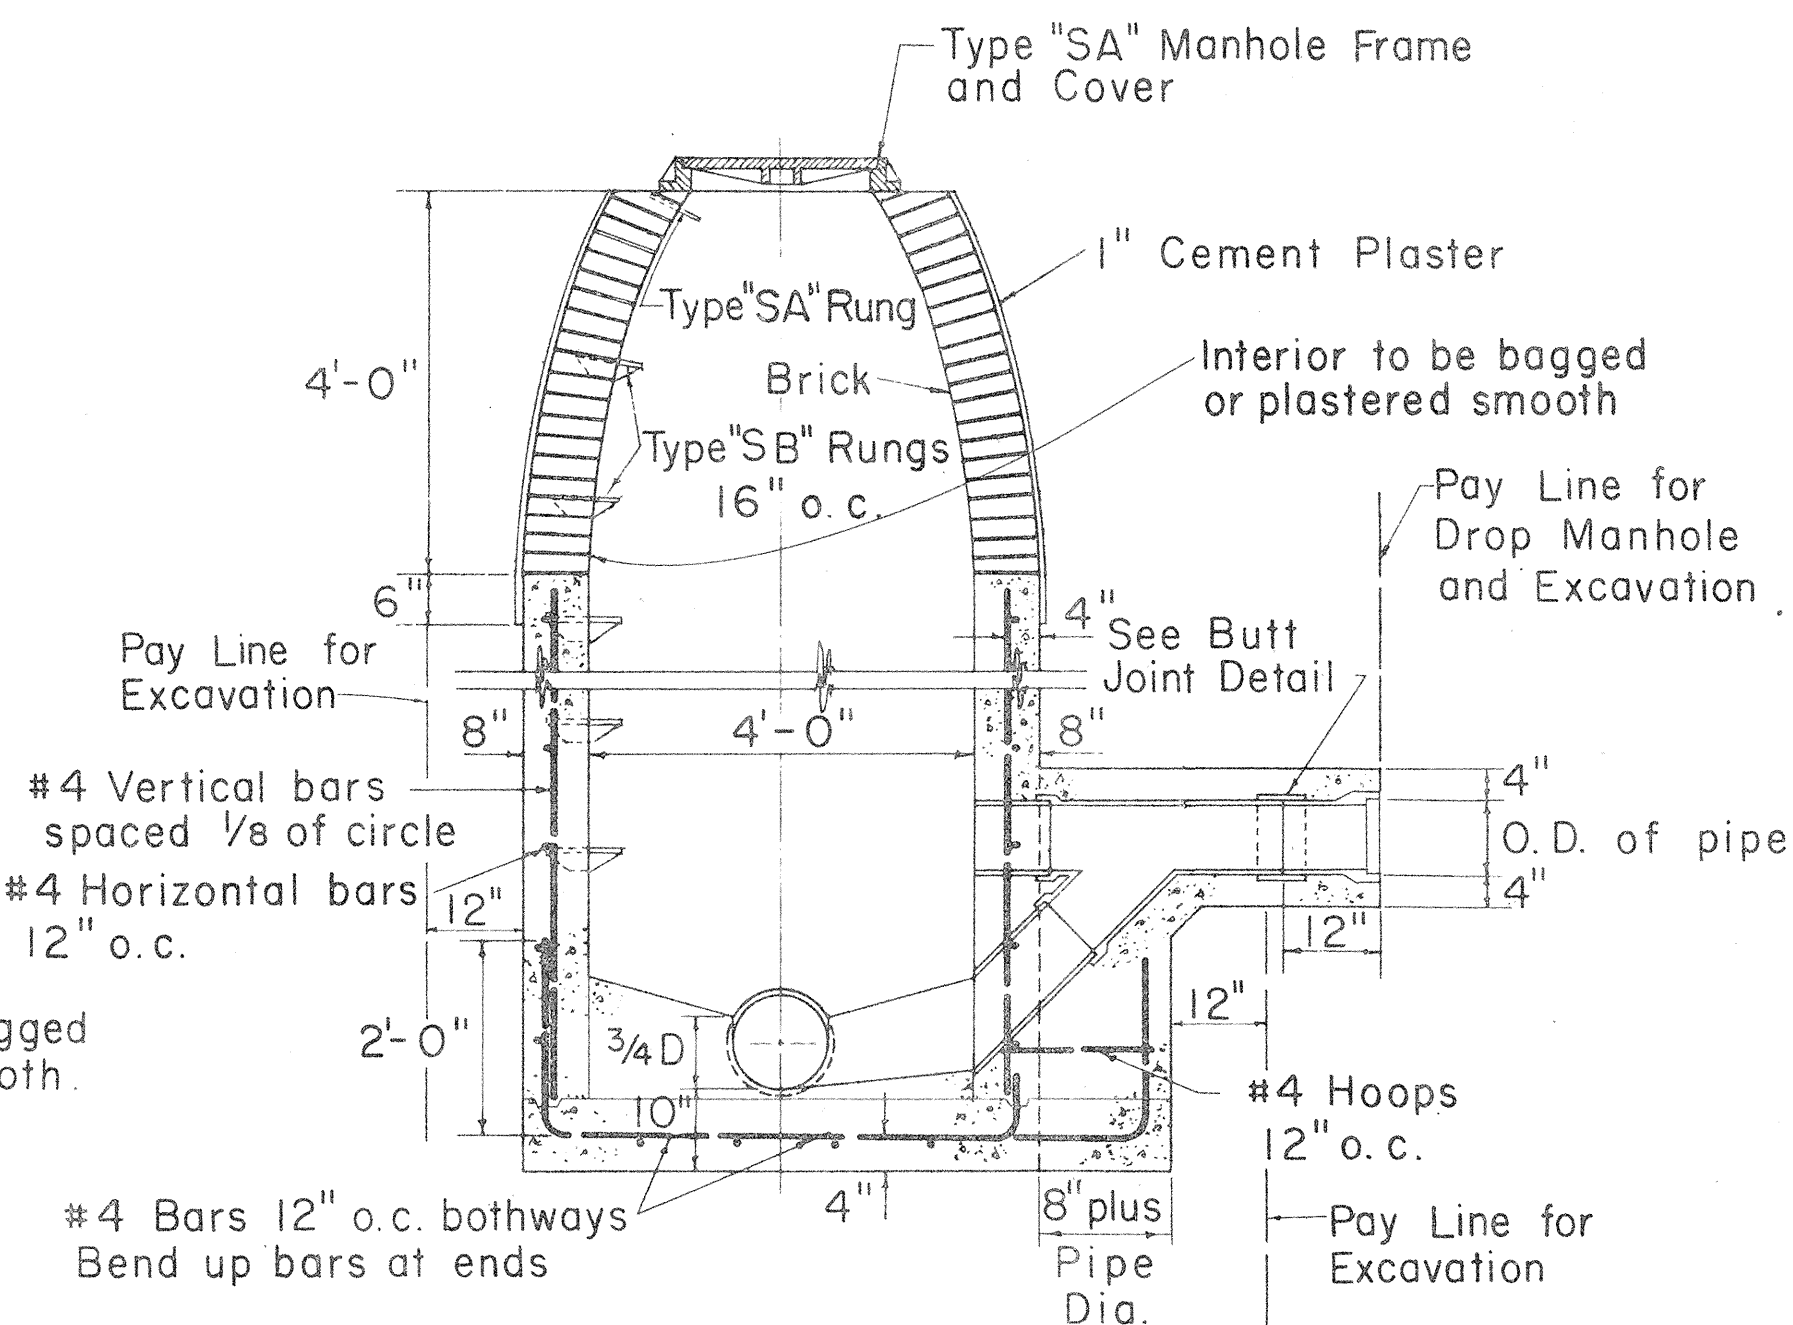

SHALLOW DROP MANHOLE
Scale: 1/2" = 1'-0"

NOTE:

1. Manhole rungs shall not be aligned above any flow line except in drop manhole.
2. No rungs shall be installed in manholes less than 3' high.
3. When not otherwise noted, manhole stubs shall be sloped as follows:

Pipe Size	Rise Per Foot
6"	1/8"
8"	3/32"
10"	1/16"
12"	1/16"


4. All reinforcing rods interfering with pipes shall be bent to clear them.
5. Bar lap to be 40 diameters in length.
6. Data for special manholes not shown shall be similar to that for plain manholes.
7. Size of drop pipe in all Drop Manholes shall be same as influent line.

APPROVED:

SEWER SYSTEM DIRECTOR,
DIVISION OF SEWERS

DATE

8/16/68

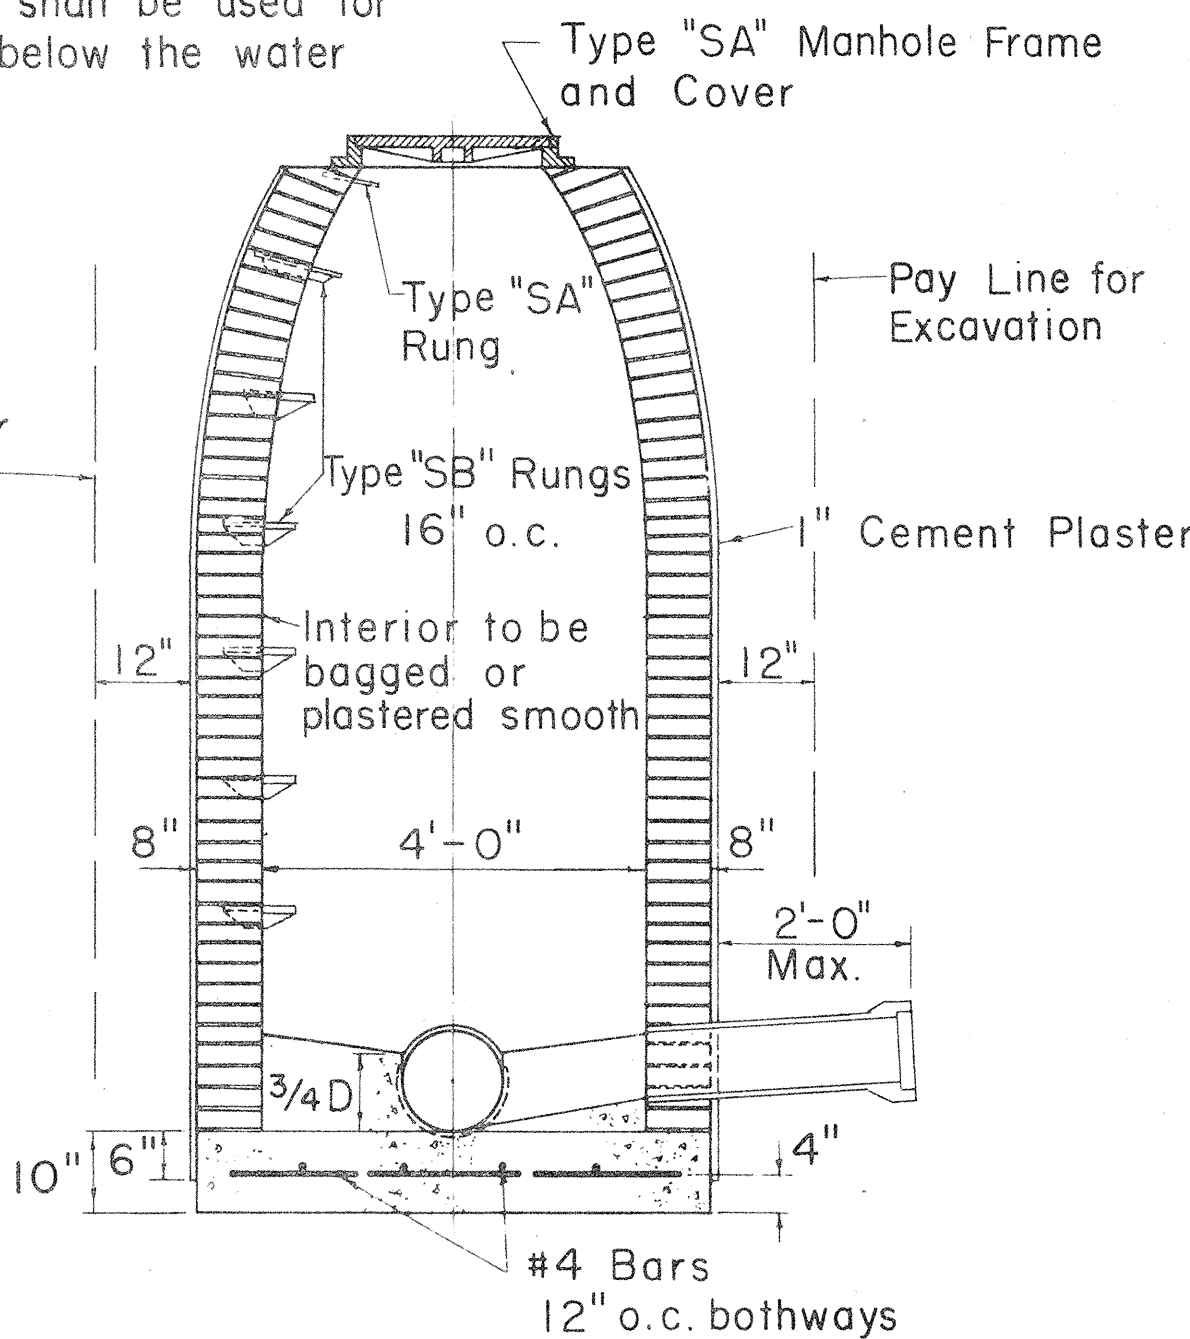

BRICK MANHOLE
Scale: 1/2" = 1'-0"

Payment for excavation for manholes shall be made under unit price for trench excavation and shall be measured to one foot outside of walls from original ground elevation to authorized bottom elevation.

Payment for manhole walls (brick, or cast-in-place concrete) shall include brick, mortar, concrete, reinforcing steel, cast-iron steps, galvanized wrought iron rungs, and plastering.

STATE OF HAWAII
DEPARTMENT OF TRANSPORTATION
HIGHWAYS DIVISION
DIVISION OF SEWERS
CITY & COUNTY OF HONOLULU

STANDARD DETAILS


SEWERS - DROP MANHOLE AND
BRICK MANHOLE DETAILS

Scales: As Noted


Date: 8/16/68

SHEET NO. 16 OF 27 SHEETS


FED. ROAD DIST. NO.	STATE	FED. AID PROJ. NO.	FISCAL YEAR	SHEET NO.	TOTAL SHEETS
HAWAII	HAWAII	1-111(64)12 UNIT 2 1-111(66)11	1969	65	128

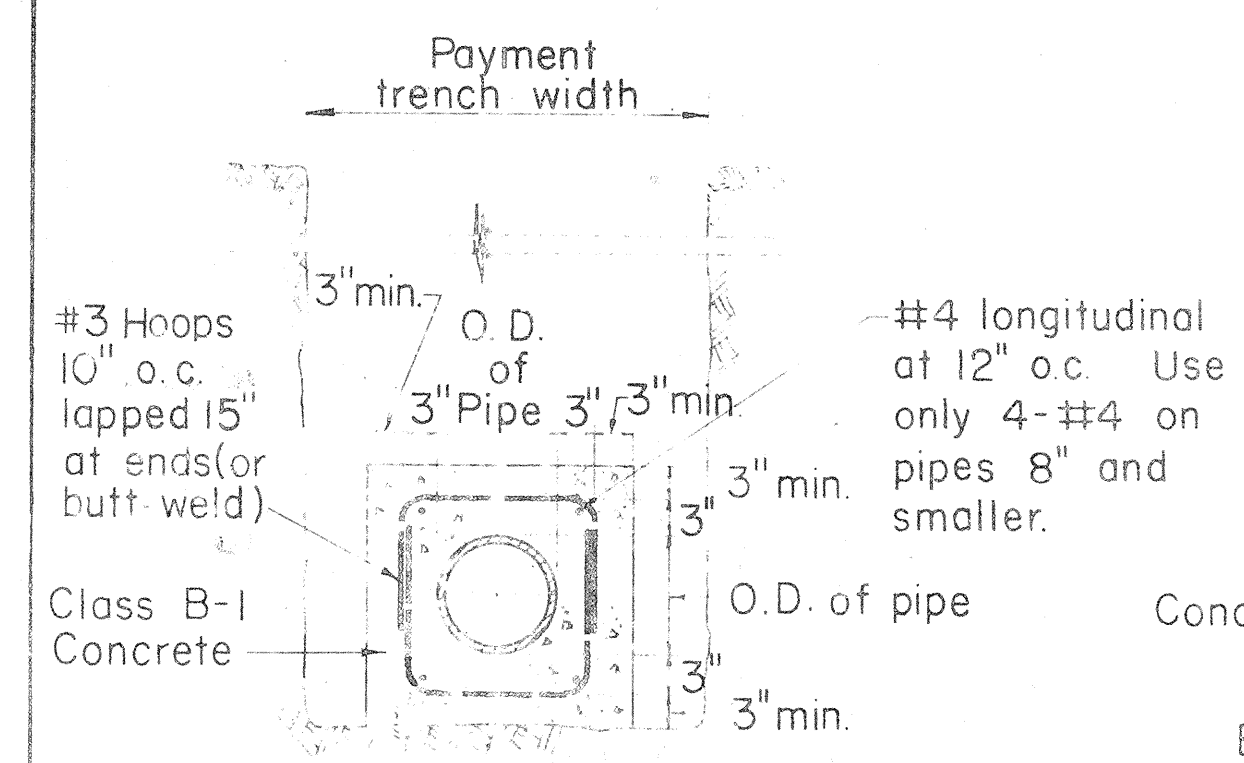


DETAIL OF CONCRETE JACKET
Scale: 3/4" = 1'-0"

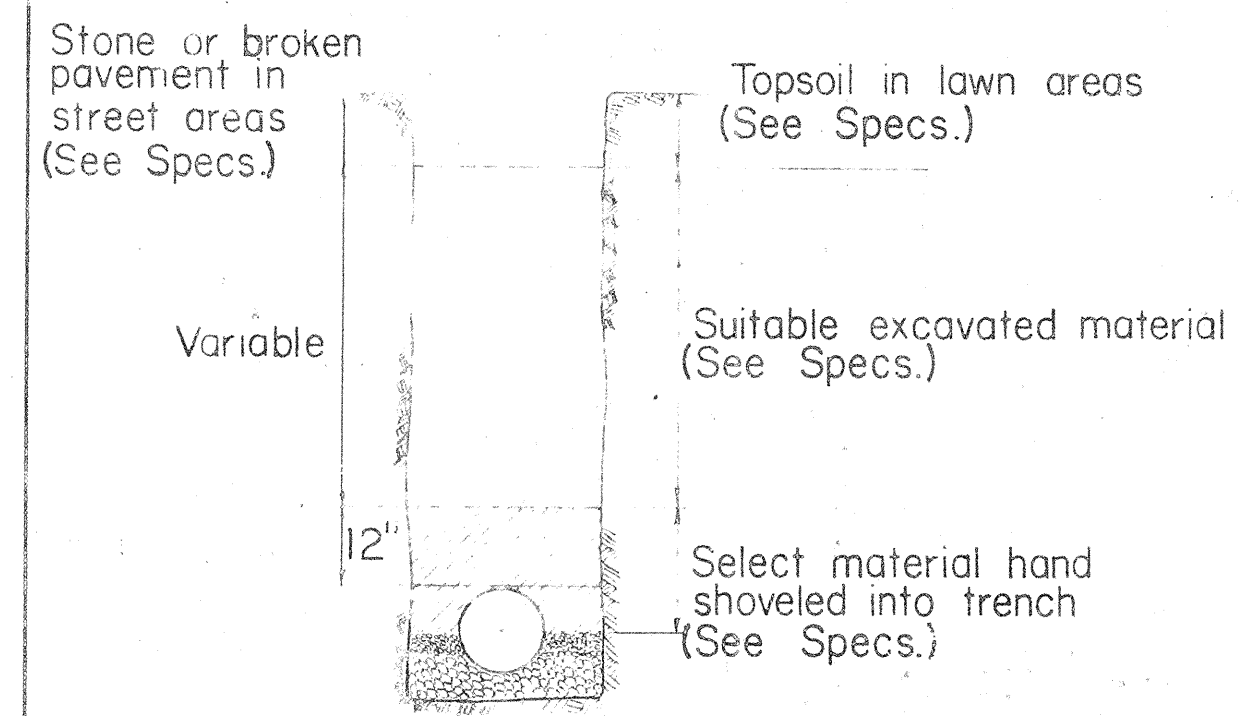

METHOD OF BACKFILL
Not To Scale

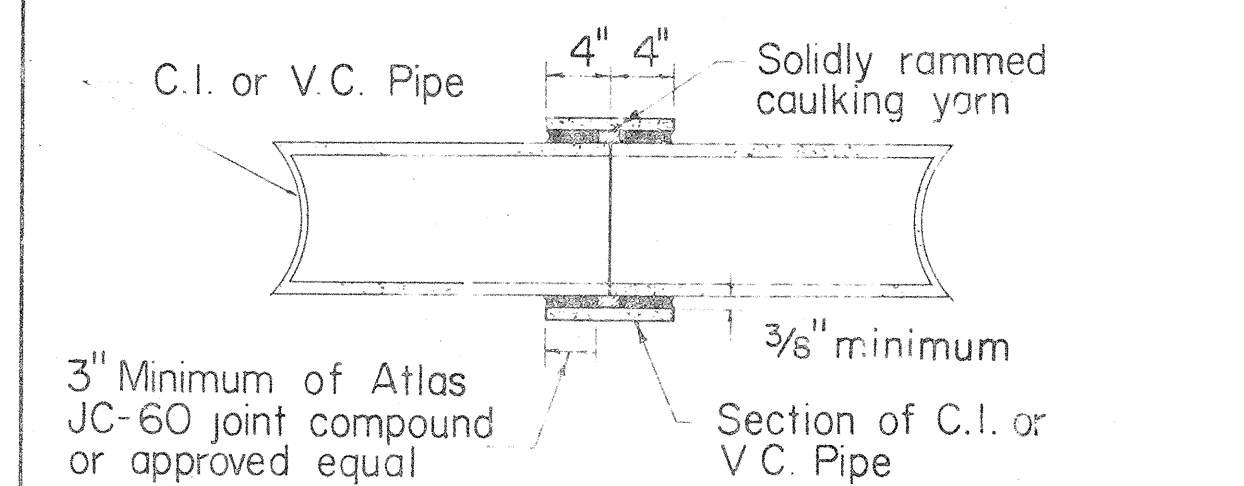


BUTT JOINT DETAIL
Scale: 1" = 1'-0"

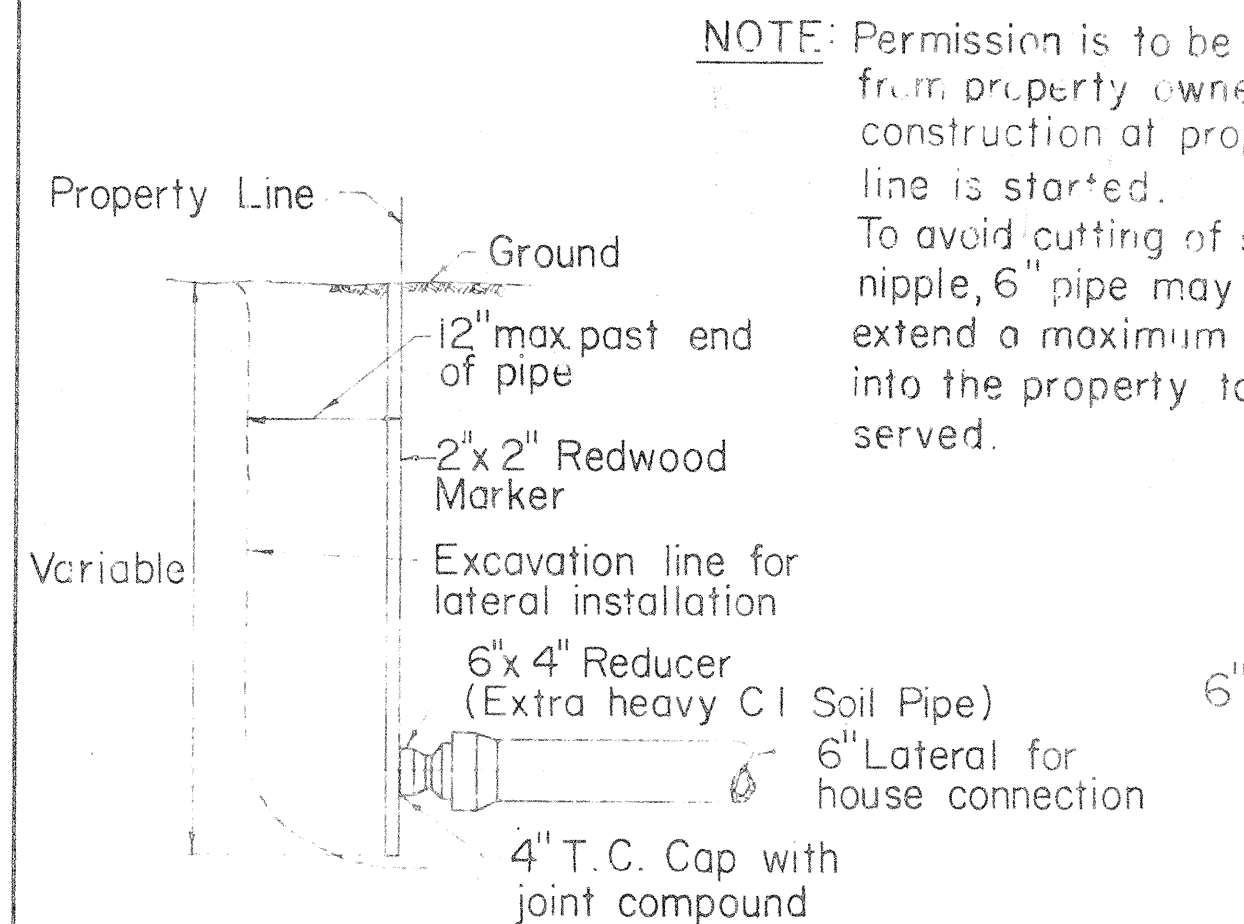


DETAIL AT PROPERTY LINE

CONSTRUCTION OF LATERALS
Not To Scale


METHOD OF USING BRICKS UNDER CONCRETE BLOCKS
Not To Scale

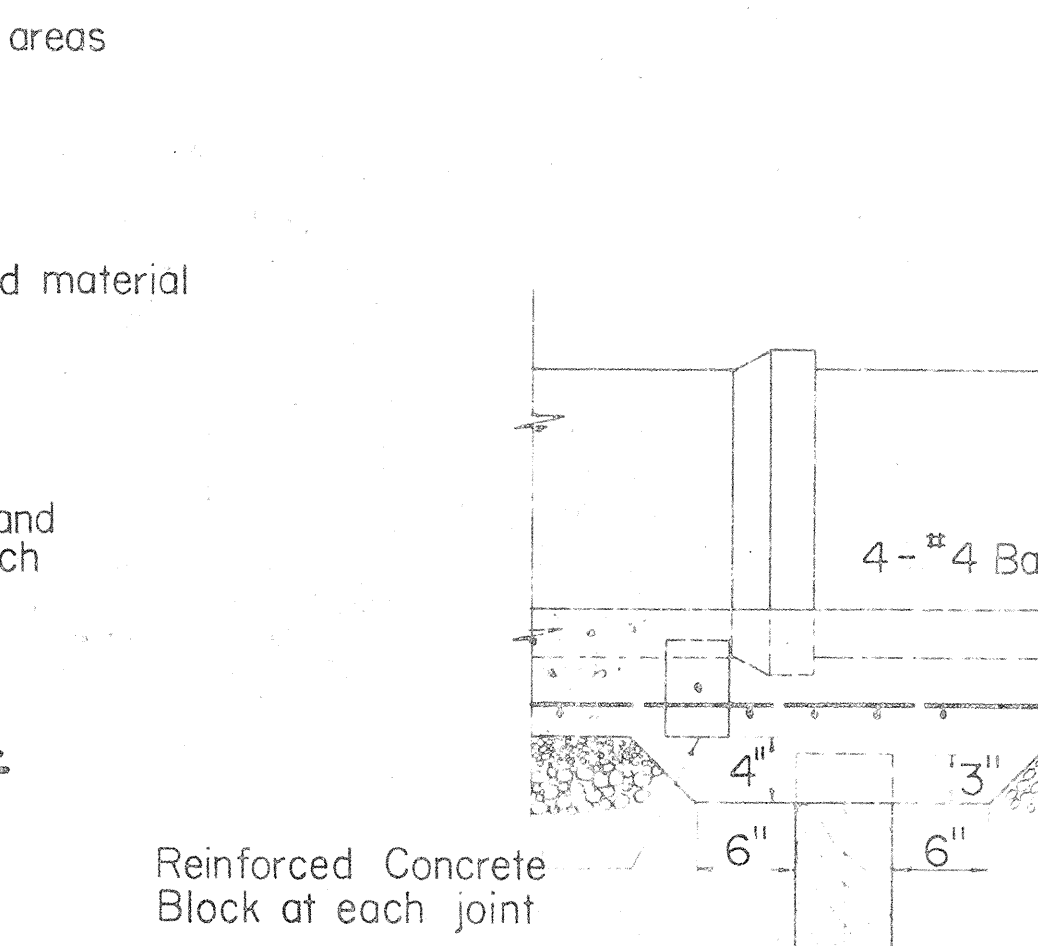

Contractor shall see Concrete Blocks on undisturbed ground. Where ground is too low, the contractor shall not heap up dirt under the Concrete Block but use Concrete Bricks to take up the deficiency, scraping away beneath Concrete Block to give sufficient room for Brick.

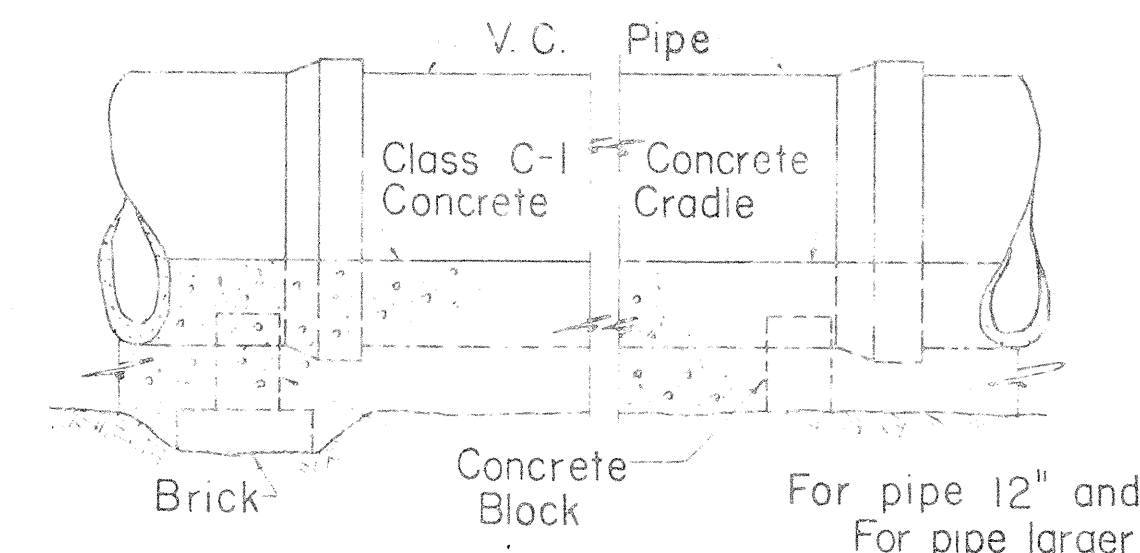


ELEVATION SHOWING METHOD OF LAYING PIPE
Not To Scale

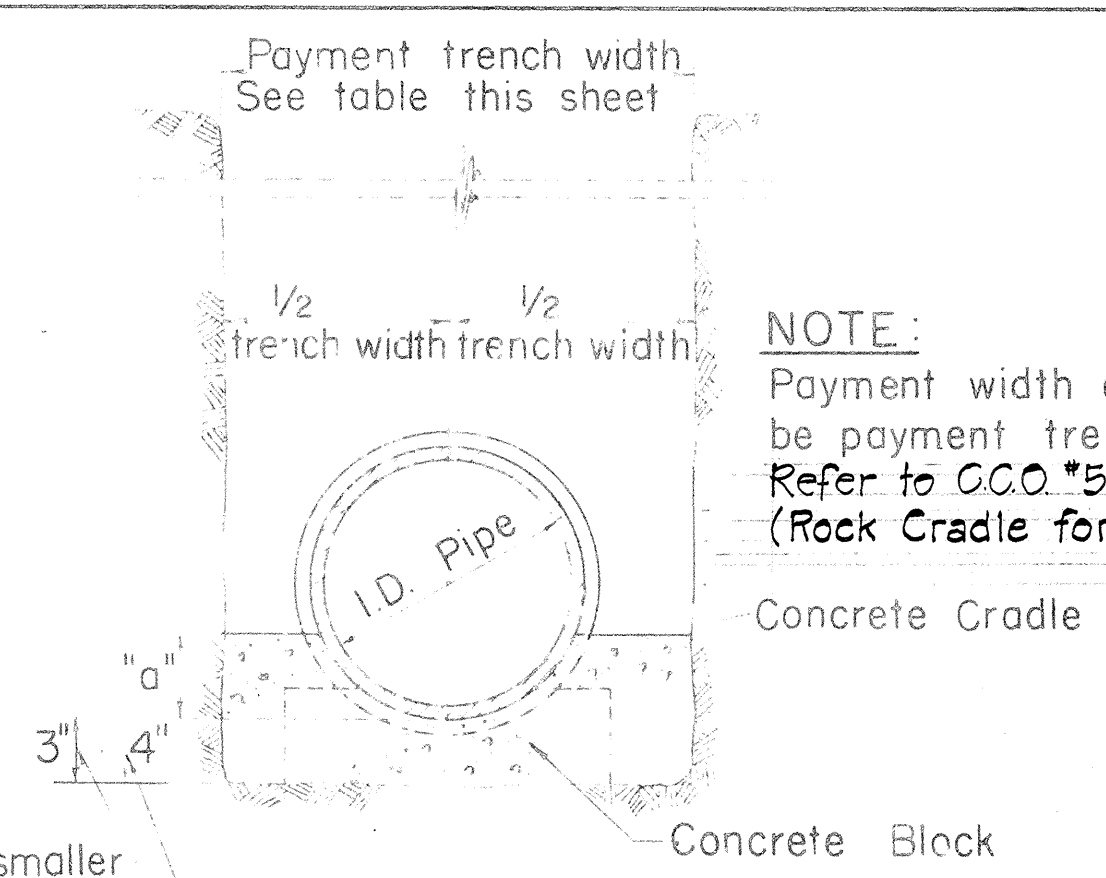


CONCRETE CRADLE FOR VITRIFIED CLAY PIPE
Not To Scale

NOTE:
Payment width of cradle shall be payment trench width. Refer to C.C.O. #5. See detail, sht. no. 63. (Rock Cradle for Vitrified Clay Pipe)

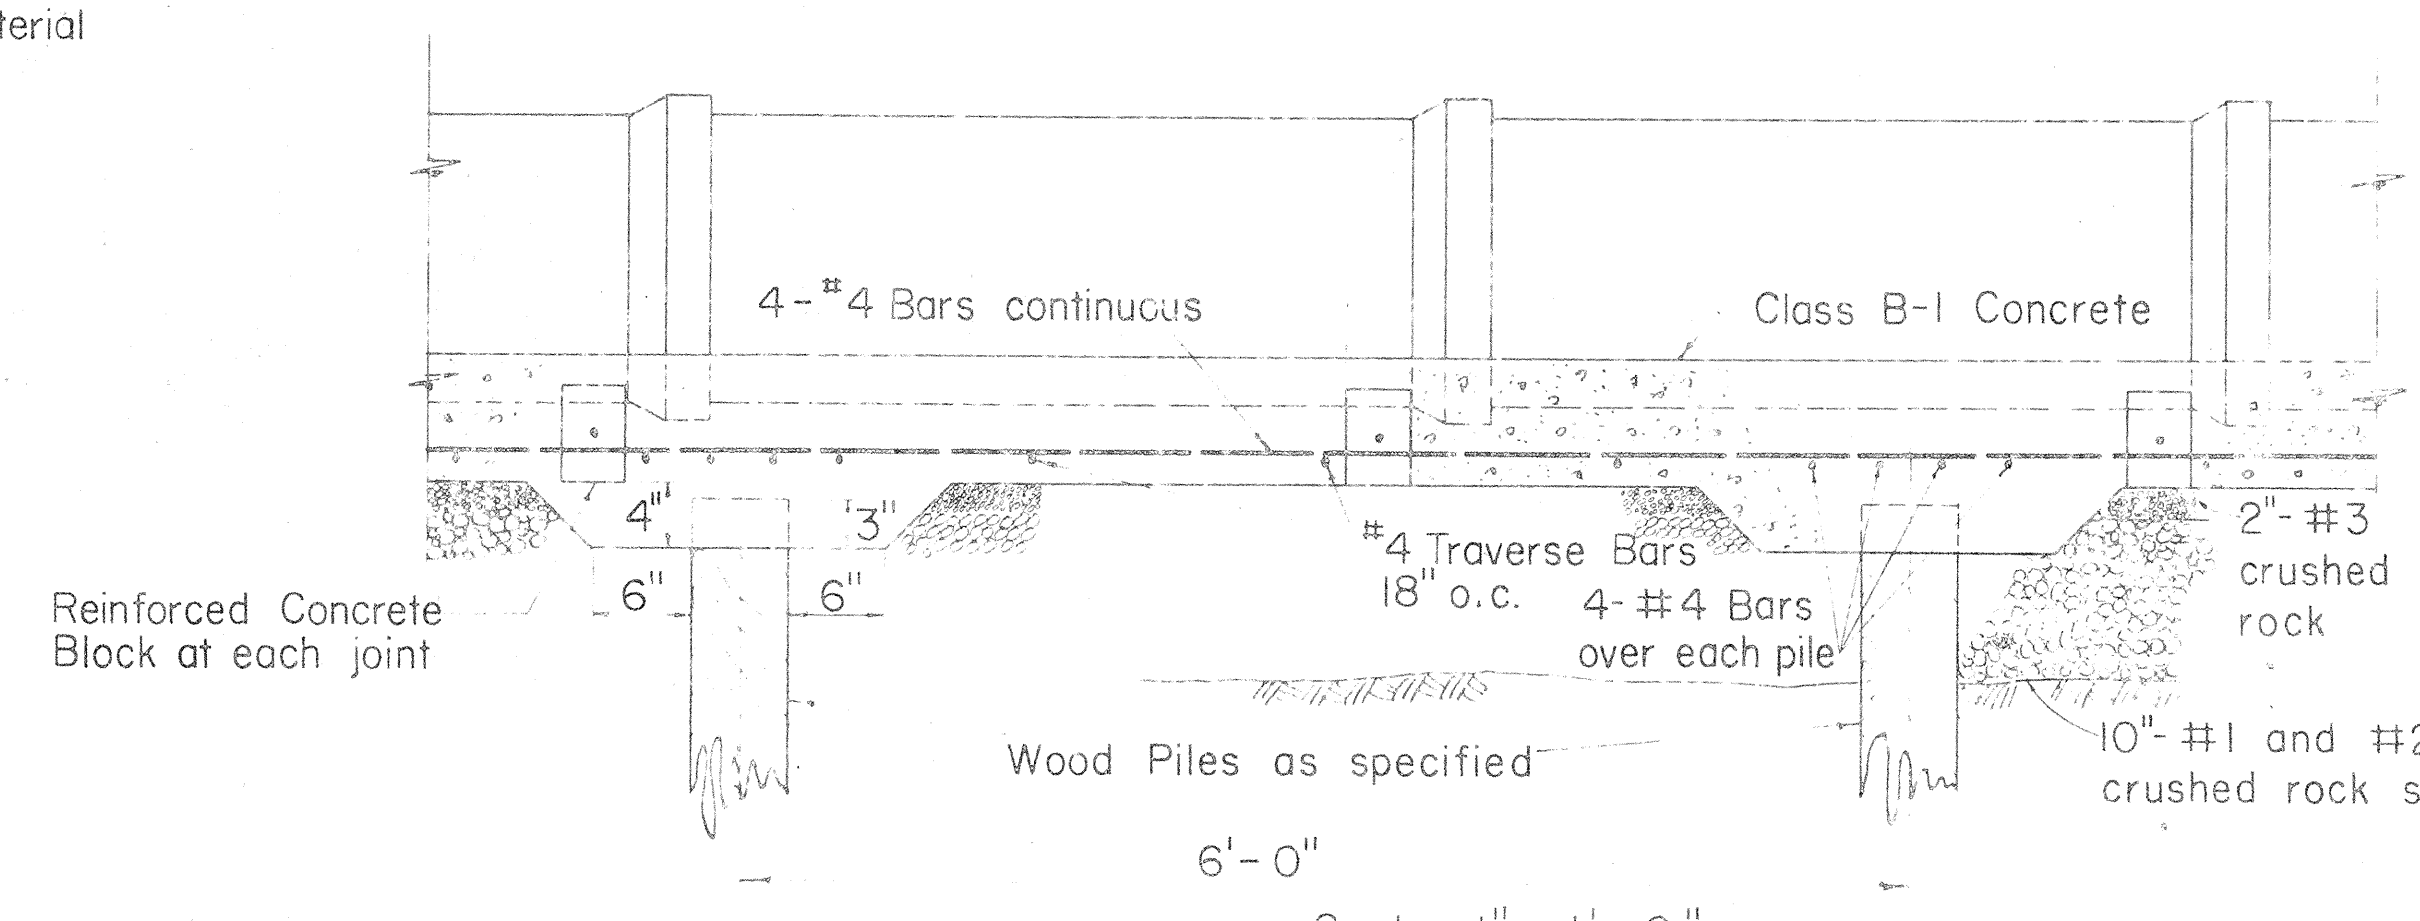


DETAIL OF REINFORCED CONCRETE CRADLE ON WOOD PILES (FOR 6, 8, 10 & 12 IN. V.C. PIPE)
Scale: 1" = 1'-0"

DETAIL OF REINFORCED CONCRETE CRADLE WITHOUT PILES SIMILAR EXCEPT FOR WOOD PILES AND PILE CAPS

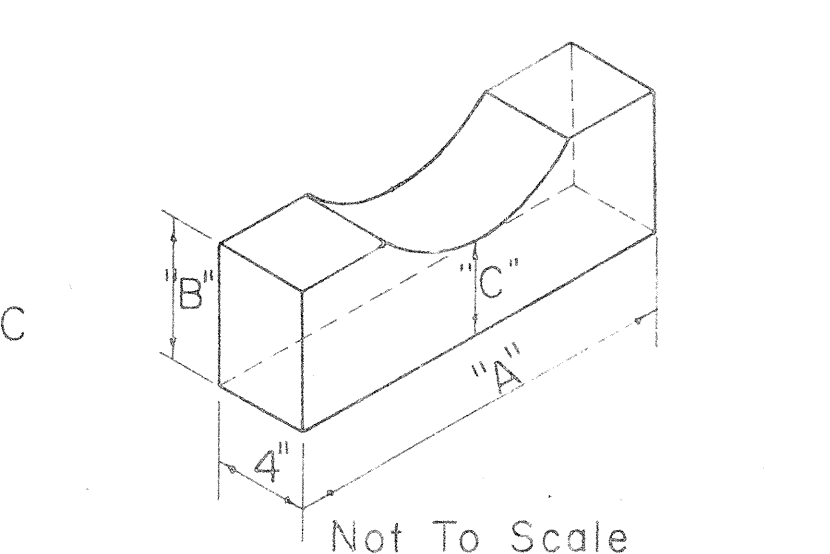


DETAIL OF PRECAST CONC. PIPE BLOCK

PIPE SIZE	"A"	"B"	"C"
6"	1'-2"	6"	3"
8"	1'-5"	6"	3"
10"	1'-7"	6"	3"
12"	1'-7"	6"	3"
15"	1'-8"	6"	4"
18"	1'-9"	6"	4"
21"	1'-10"	6"	4"
24"	1'-11"	6"	4"
27"	2'-0"	6"	4"
30"	2'-3"	6"	4"

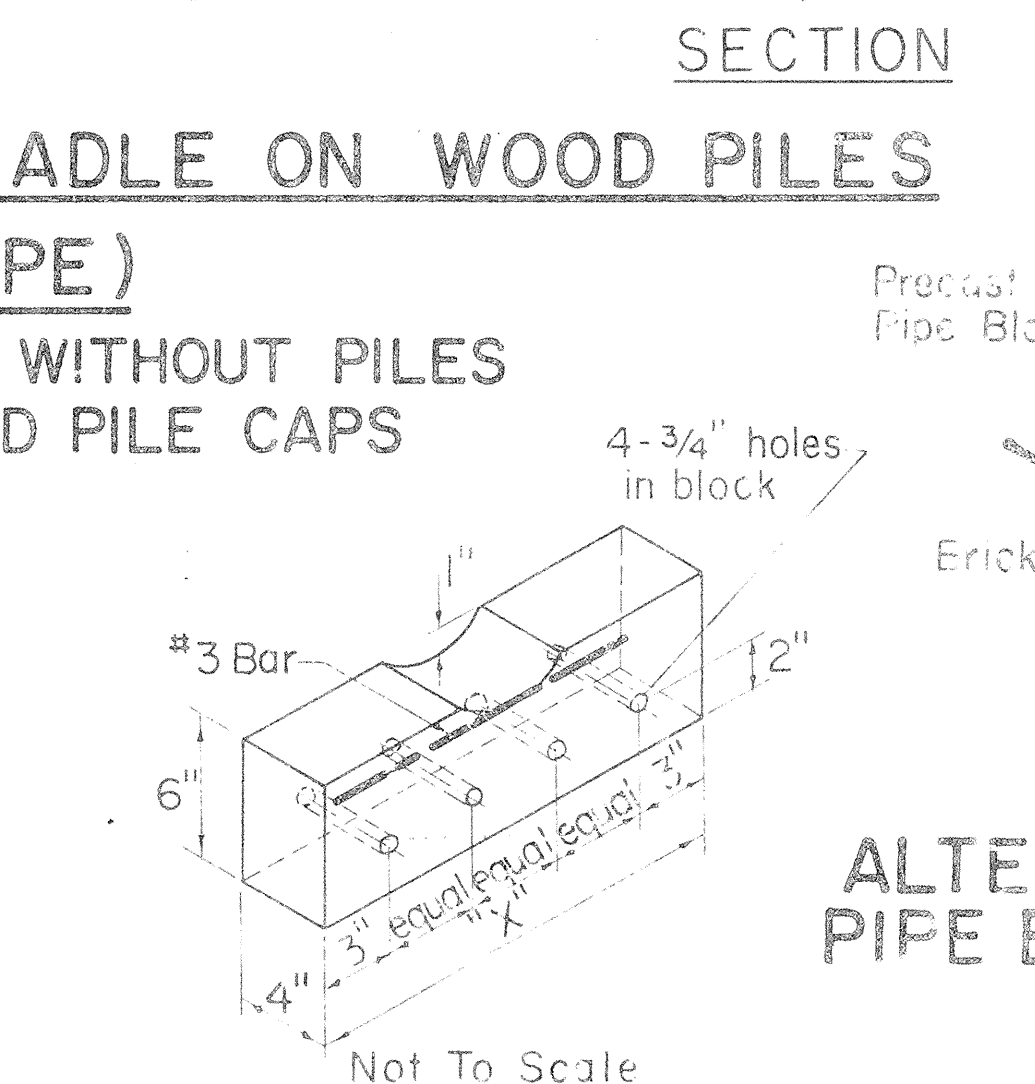


DETAIL OF CONC. PIPE BLOCK FOR REINF. CRADLE

PIPE SIZE	"X"
6"	1'-6"
8"	1'-6"
10"	1'-8"
12"	1'-8"
15"	1'-10"
18"	1'-10"
21"	1'-10"
24"	2'-0"
27"	2'-0"
30"	2'-0"

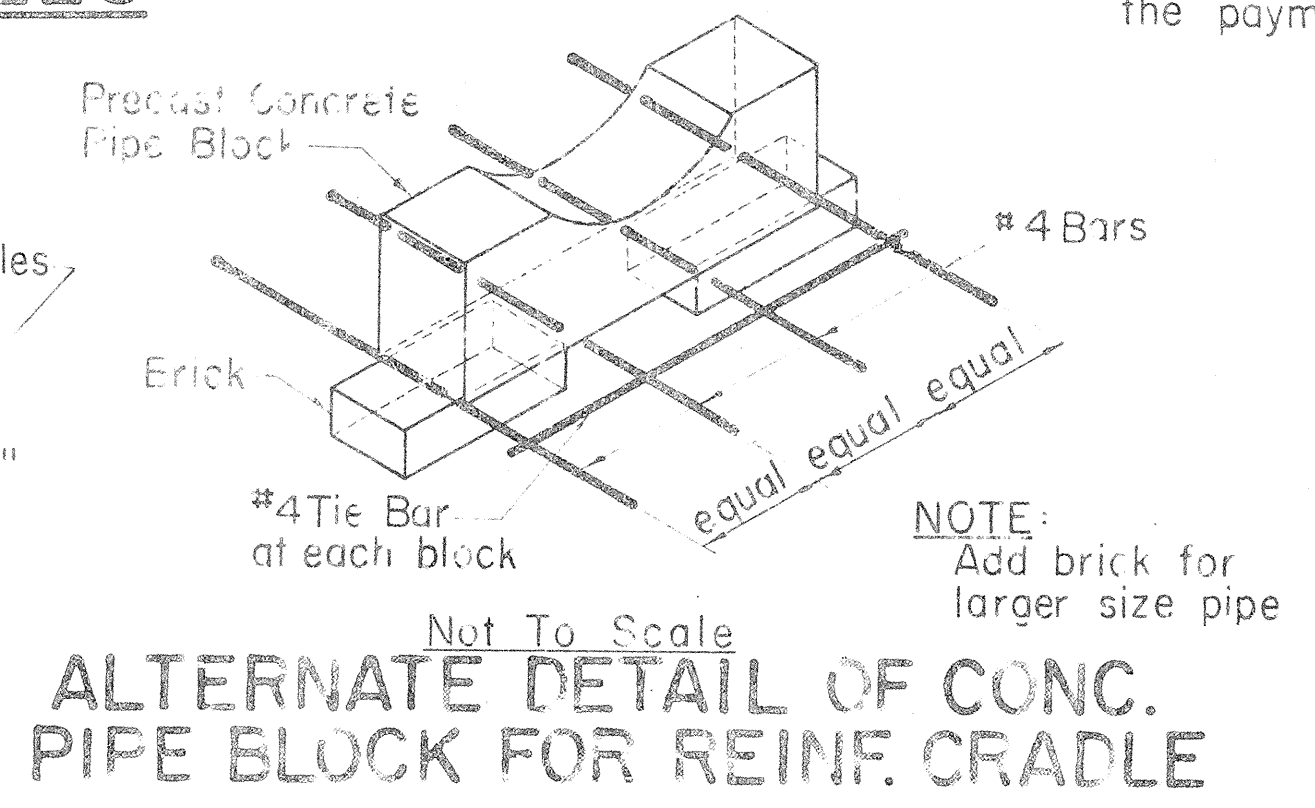

ALTERNATE DETAIL OF CONC. PIPE BLOCK FOR REINF. CRADLE

APPROVED:
for SEWER SYSTEM DIRECTOR, DIVISION OF SEWERS
DATE 8/16/68

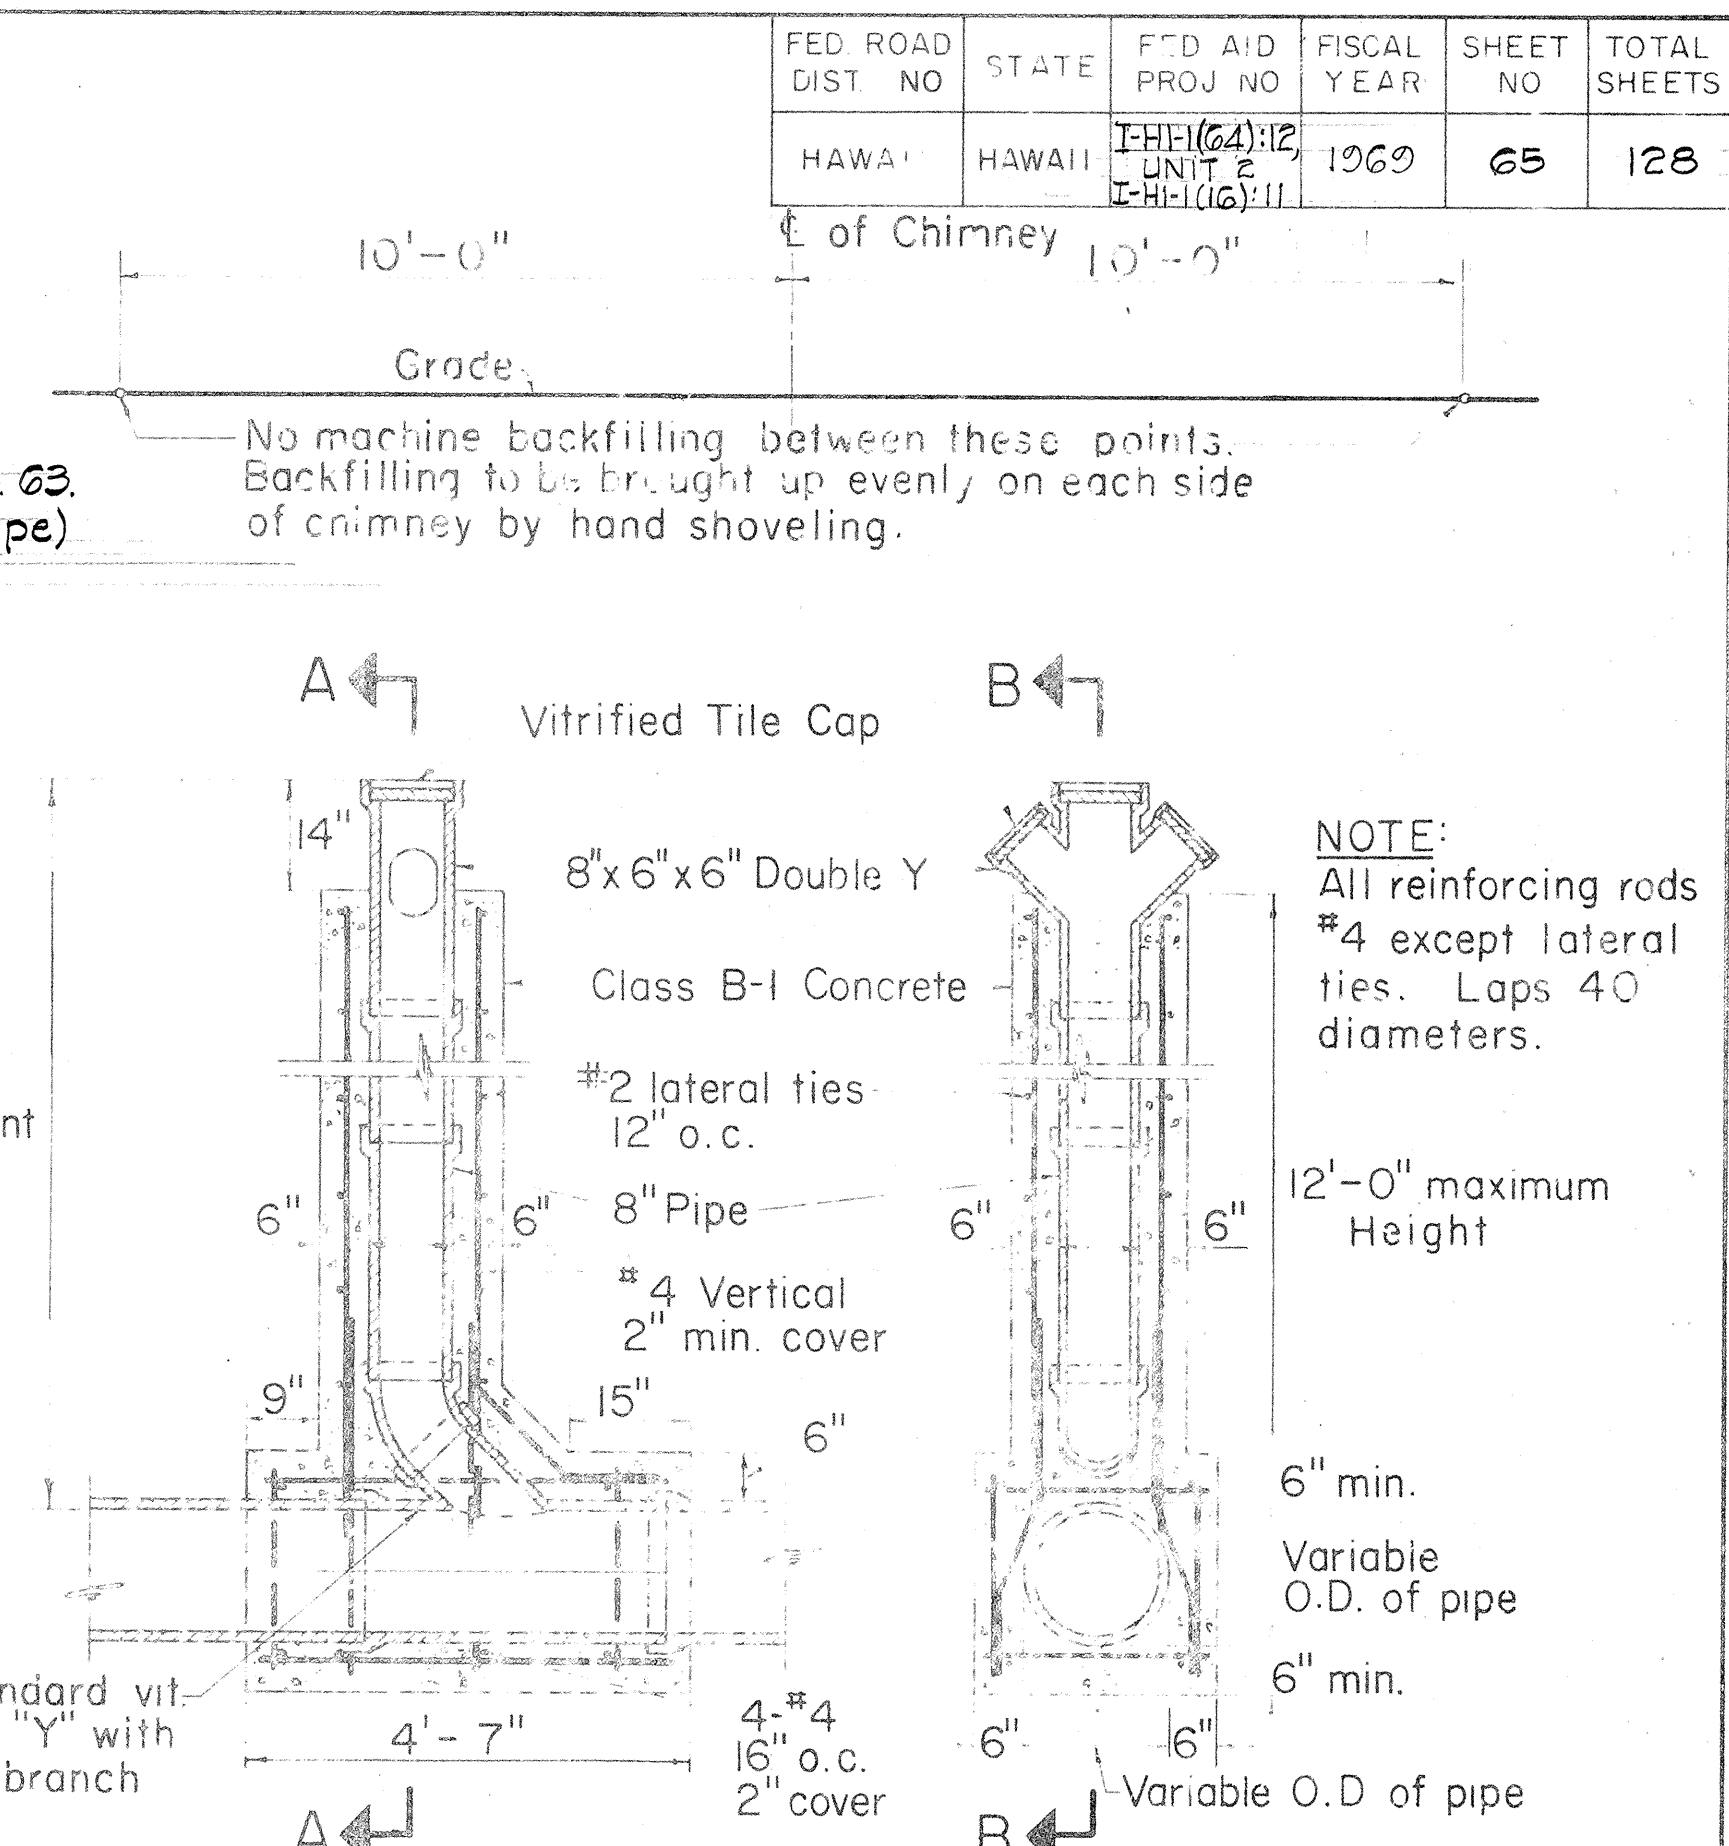

SECTION B-B SECTION A-A DETAILS OF CHIMNEY
Scale: 1/2" = 1'-0"

Payment quantities for trench excavation, crushed rock fill, crushed rock cradle, and crushed rock sub-base shall be computed using payment trench widths as shown in the table of "Trench Widths". No payment shall be made for excess quantities resulting from trench widths greater than the payment trench widths shown.

VITRIFIED CLAY PIPE TABLE

TRENCH WIDTHS		DIM. OF CONC. CRADLE	
PIPE SIZE	PAY. WIDTH	PIPE SIZE	WIDTH
6"	24"	6"	3"
8"	24"	8"	3"
10"	24"	10"	3"
12"	30"	12"	3"
15"	38"	15"	4"
18"	41"	18"	5"
21"	45"	21"	5"
24"	50"	24"	6"
27"	53"	27"	7"
30"	57"	30"	7"


STATE OF HAWAII
DEPARTMENT OF TRANSPORTATION
HIGHWAYS DIVISION
DIVISION OF SEWERS
CITY & COUNTY OF HONOLULU

STANDARD DETAILS

SEWERS-CONCRETE JACKET & MISCELLANEOUS DETAILS

Scales: As Noted Date: 8/16/68

SHEET NO. 17 OF 27 SHEETS

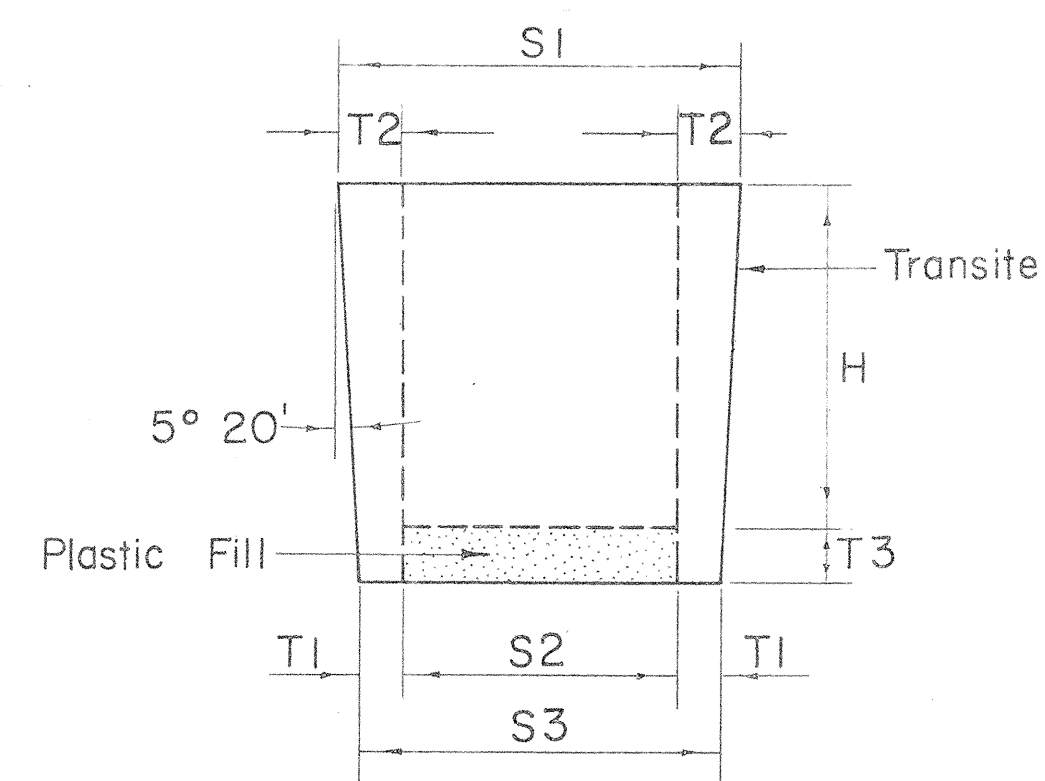

PLUGS FOR TRANSITE KORDUCTS

Not to Scale

SIZE	H	S1	S2	S3	T1	T2	T3
3"	4"	3 3/8"	2"	2 5/8"	5 1/16"	11 1/16"	3 3/4"
4"	4 1/2"	4 27/64"	2 3/4"	3 37/64"	13 1/32"	27 1/32"	3 3/4"
4 1/2"	4 1/2"	4 59/64"	3"	4 5/64"	35 1/64"	31 1/32"	3 3/4"
5"	4 1/2"	5 27/64"	3 1/2"	4 37/64"	35 1/64"	31 1/32"	3 3/4"


JUNIOR END BELLS

Not to Scale

SIZE	D1	D2	F	X	E	R
3"	3 25/64"	4 1/2"	1 11/32"	29 1/32"	1 1/4"	1 3/4"
4"	4 25/64"	5 3/4"	1 9/16"	1 9/16"	3 3/8"	2"
4 1/2"	4 57/64"	6 1/4"	1 9/16"	1 9/16"	3 3/8"	2"
5"	5 29/64"	7"	1 9/16"	1 7/16"	1 1/2"	2"

Note "X"

- Provide one set of Spacers
 (a) 10 Ft. straight run for 4 Ducts high or less.
 (b) 5 Ft. straight run for 5 Ducts high or more.

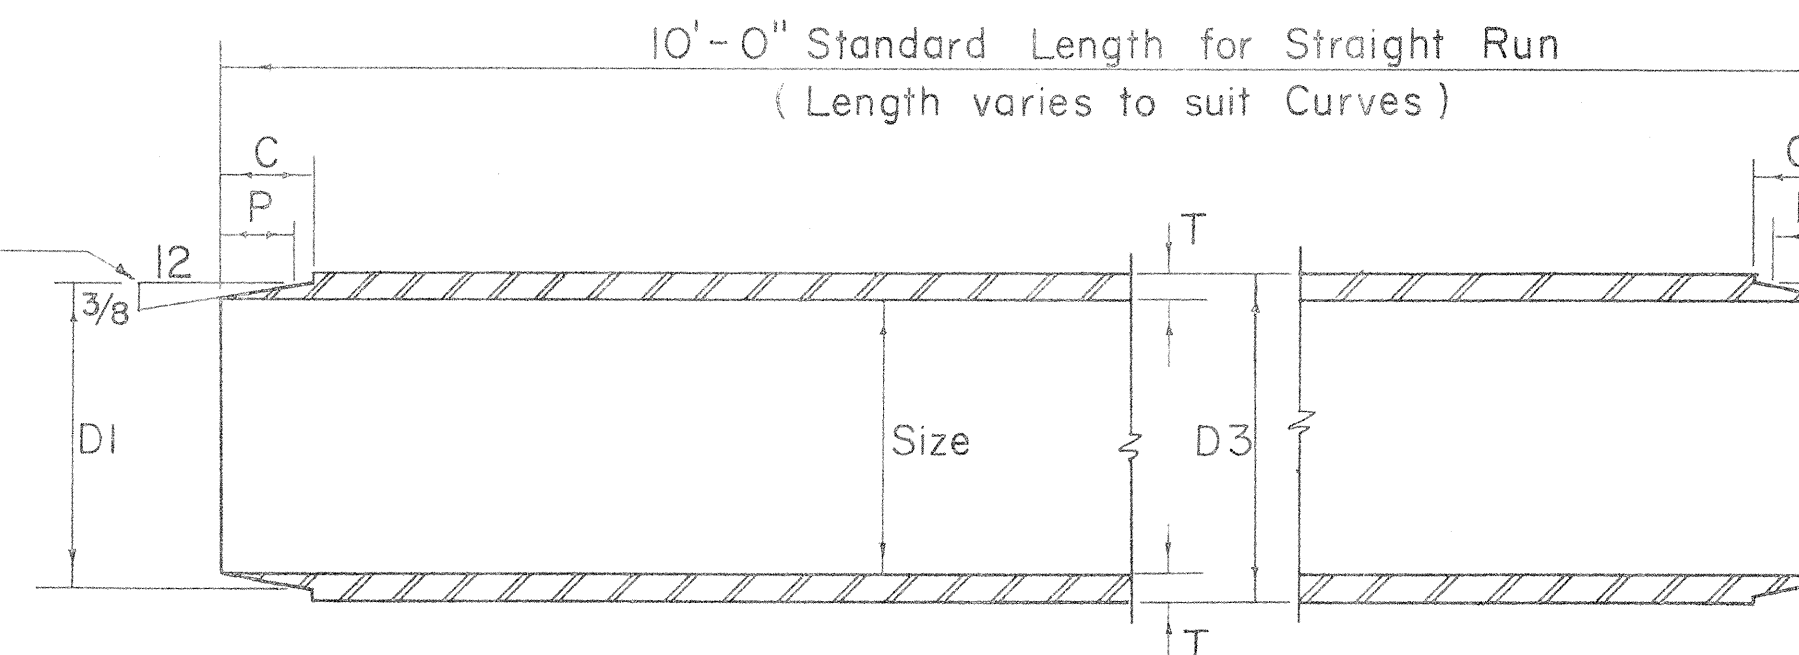

TRANSITE KORDUCTS


Not to Scale

SIZE	D1	D3	C	P	T
3"	3 25/64"	3 35/64"	1 1/8"	7 7/8"	17 1/64"
4"	4 25/64"	4 35/64"	1 1/4"	1"	17 1/64"
4 1/2"	4 57/64"	5 3/64"	1 1/4"	1"	17 1/64"
5"	5 29/64"	5 39/64"	1 1/8"	1 1/8"	19 1/64"

TAPERED COUPLINGS


Not to Scale

SIZE	D1	D2	L
3"	3 25/32"	4 11/64"	2 1/4"
4"	4 25/64"	5 3/16"	2 1/2"
4 1/2"	4 57/64"	5 49/64"	2 1/2"
5"	5 29/64"	6 21/64"	2 3/4"

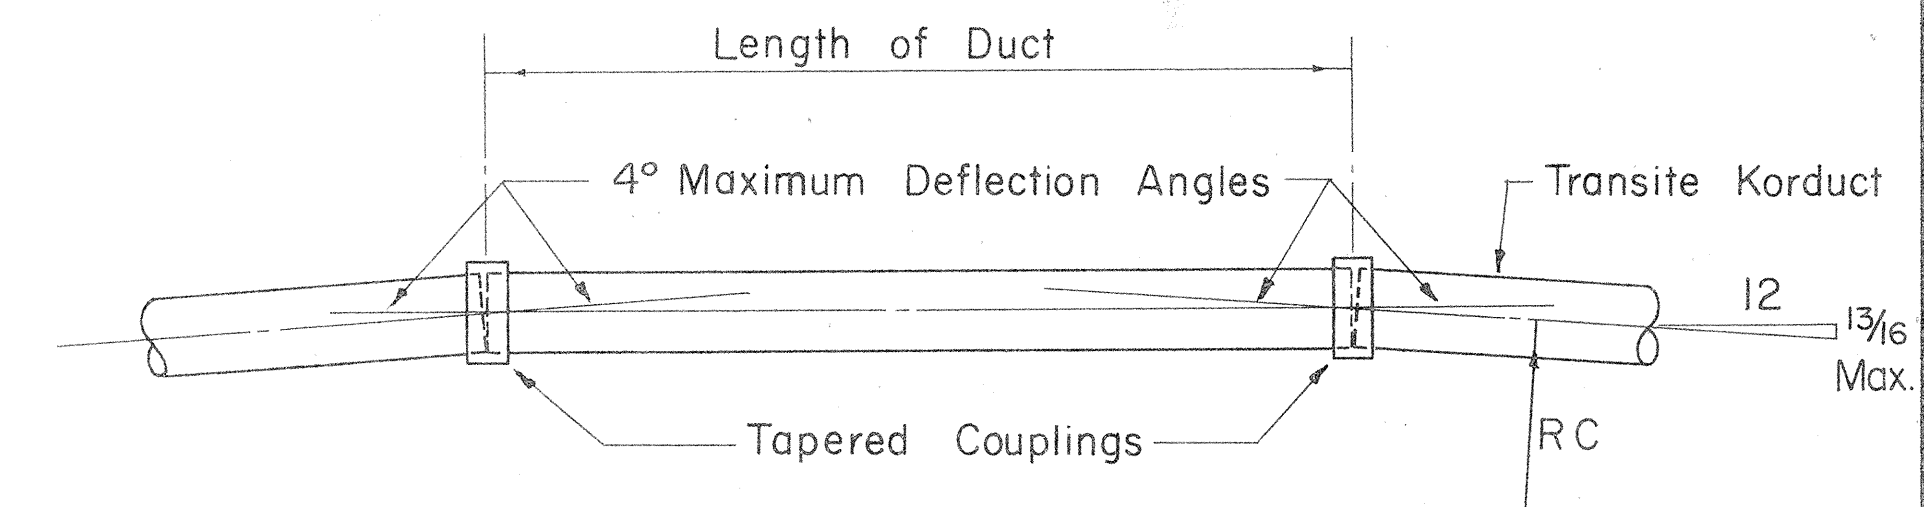

METHOD OF FORMING CURVES


Not to Scale

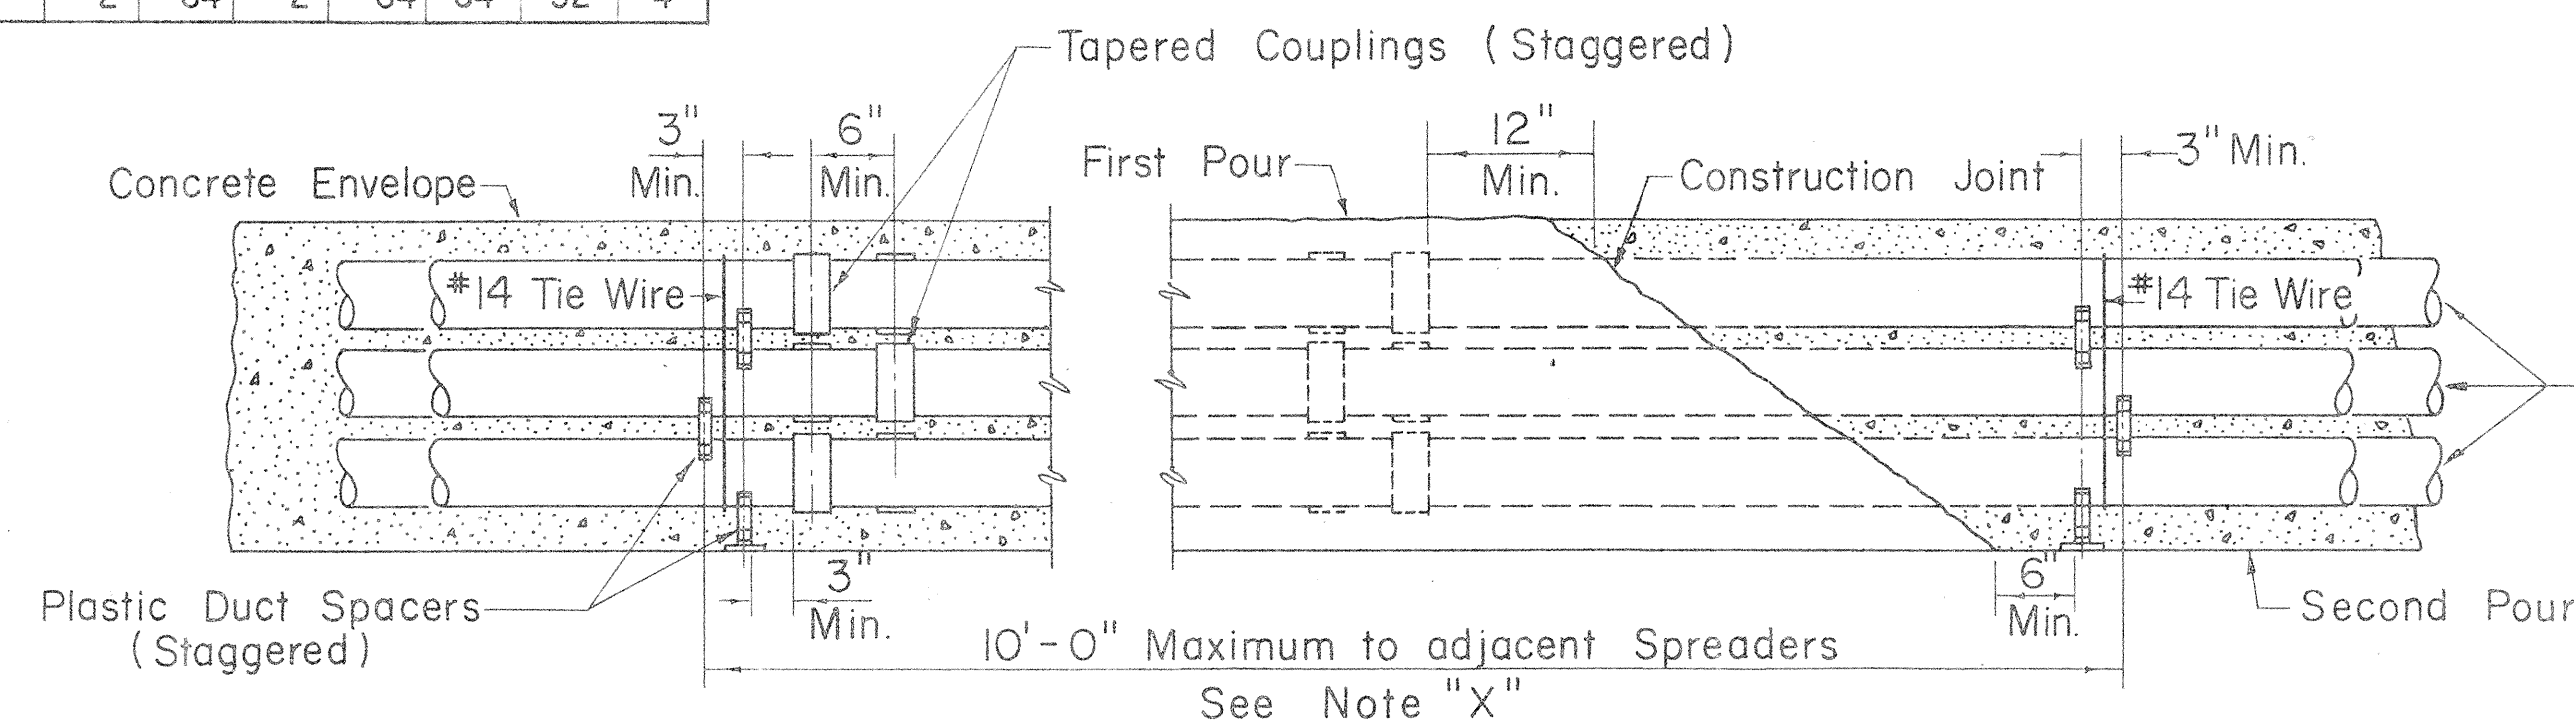

TYPICAL DUCT ENVELOPE ELEVATION

(6 WAY DUCT LINE SHOWN)


Not to Scale

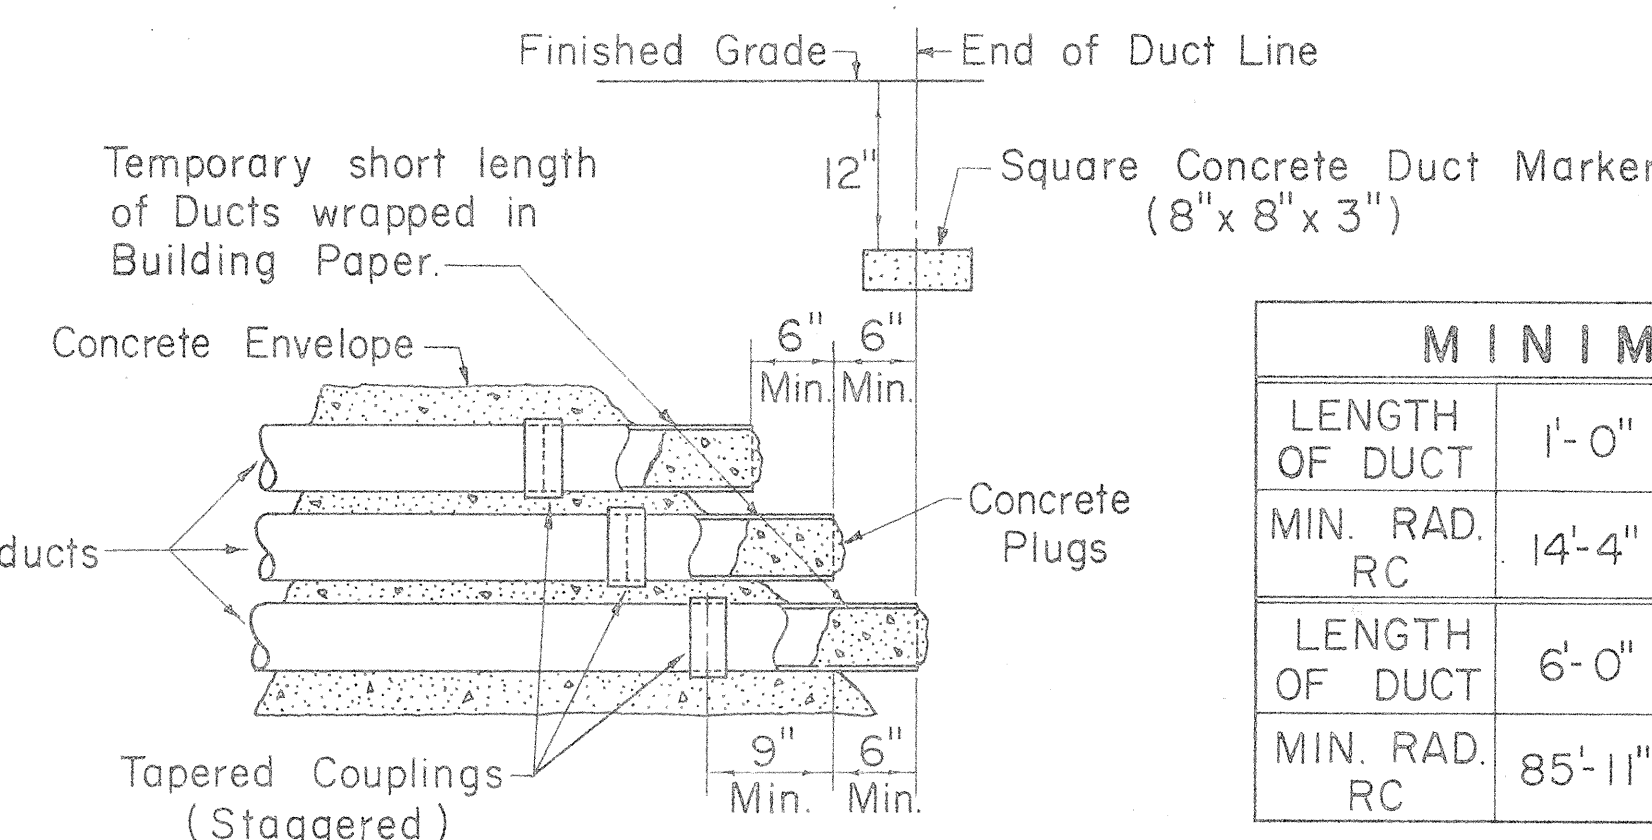

TYPICAL STUB OUT DETAIL


Not to Scale

	1'-0"	1'-6"	2'-0"	2'-6"	3'-0"	3'-6"	4'-0"	4'-6"	5'-0"	5'-6"
LENGTH OF DUCT	1'-0"	1'-6"	2'-0"	2'-6"	3'-0"	3'-6"	4'-0"	4'-6"	5'-0"	5'-6"
MIN. RAD. RC	14'-4"	21'-6"	28'-8"	35'-10"	42'-11"	50'-1"	57'-3"	64'-5"	71'-7"	78'-9"
LENGTH OF DUCT	6'-0"	6'-6"	7'-0"	7'-6"	8'-0"	8'-6"	9'-0"	9'-6"	10'-0"	
MIN. RAD. RC	85'-11"	93'-1"	100'-3"	107'-5"	114'-7"	121'-8"	128'-10"	136'-0"	143'-2"	

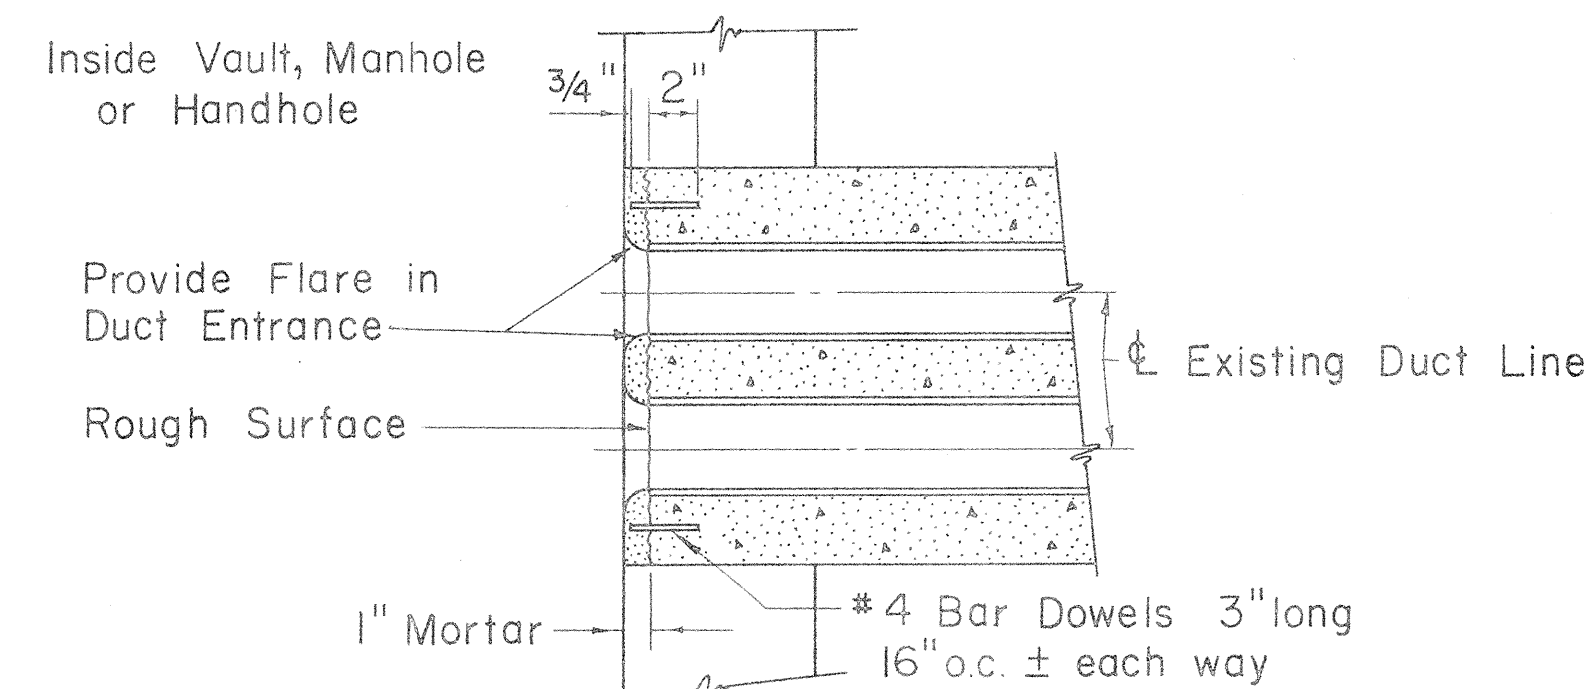

DUCT LINE ENTRANCE AT EXISTING DUCT LINE

Scale: 1 1/2" = 1'-0"

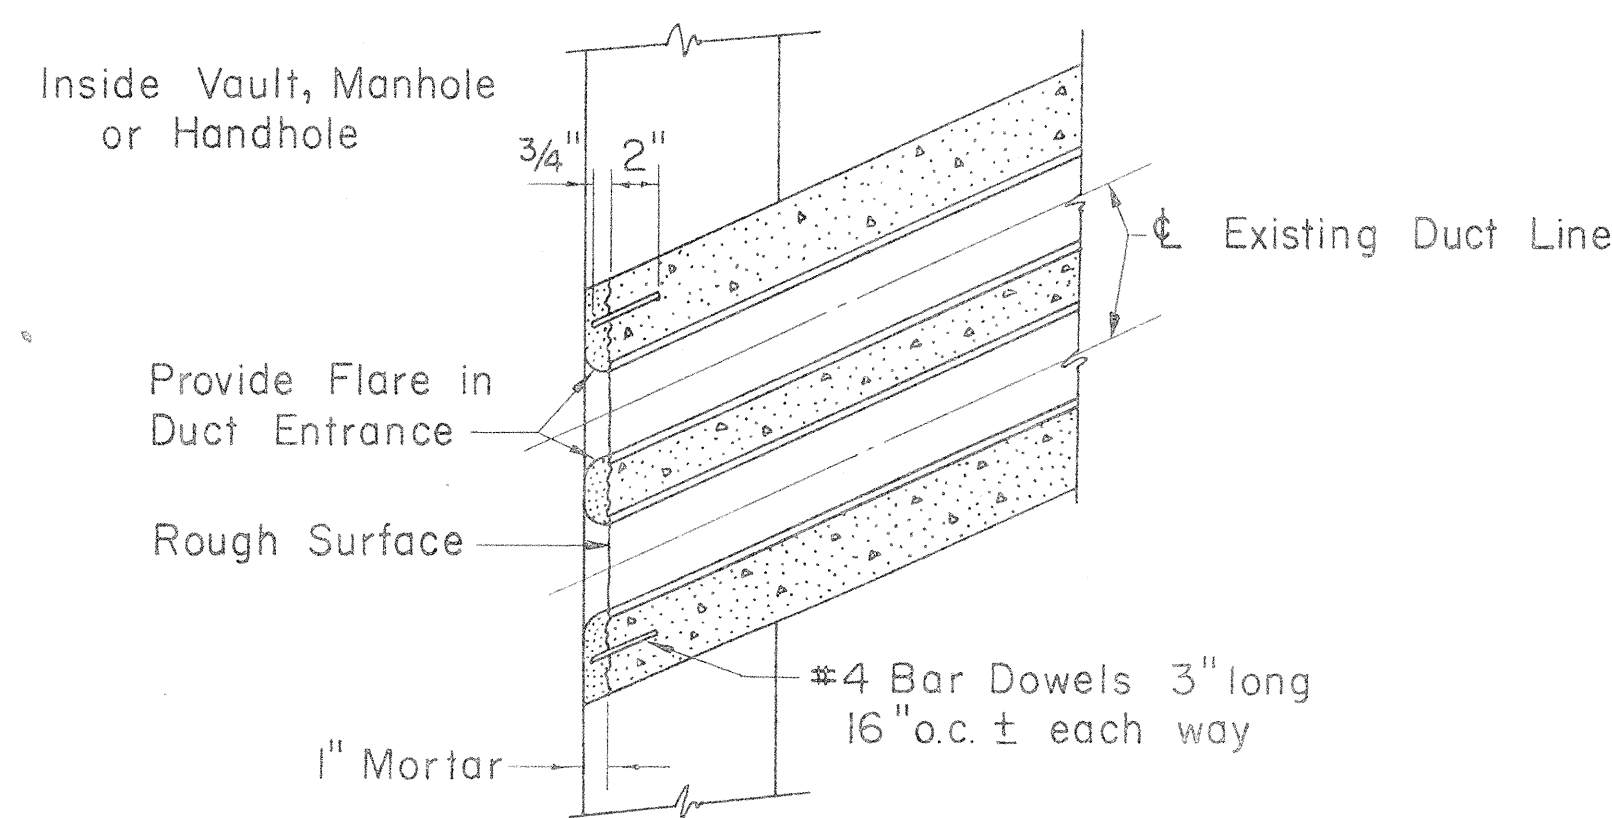

DUCT LINE DIAGONAL ENTRANCE

Scale: 1 1/2" = 1'-0"

APPROVED:

A. Henderson
HAWAIIAN ELECTRIC CO., INC.

7-20-68
DATE

HECo., Inc. Drawing Number
18585 SHEET No. 2 OF 2 SHEETS

STATE OF HAWAII
DEPARTMENT OF TRANSPORTATION
HIGHWAYS DIVISION

STANDARD DETAILS

CONSTRUCTION STANDARDS
TRANSITE KORDUCTS
UNDERGROUND DUCT LINES

Scales: As Noted

Date: 8/10/68

SHEET NO. 20 OF 27 SHEETS

68

FED. ROAD DIST. NO.	STATE	FED. AID PROJ. NO.	FISCAL YEAR	SHEET NO.	TOTAL SHEETS
HAWAII	HAWAII	1-HH-(64)-12 UNIT 2	1969	69	128

CREOSOTED DOUGLAS FIR & YELLOW PINE POLE DATA									
LENGTH IN FEET	CLASS	APPROX. MINIMUM DIMENSIONS (INCHES)				AVERAGE WEIGHT (LBS.)	POLE SETTING DEPTH (FT.)		BREAKING LOAD 2'-0" BELOW TOP OF POLE (LBS.)
		AT TOP		6' FROM BUTT		DOUGLAS FIR	IN SOIL	IN ROCK	
		DIA.	CIR.	DIA.	CIR.				
25	5	6.04	19	8.26	26	525	4.5	3	1900
30	3	7.32	23	10.32	32.5	810	5	3.5	3000
	5	6.04	19	8.90	28	600	5	3.5	1900
35	2	7.96	25	12.23	37.5	1260	5	3.5	3700
	5	6.04	19	9.55	30	770	5	3.5	1900
40	3	7.32	23	11.77	37	1320	5.5	3.5	3000
45	2	7.96	25	13.20	41.5	1845	6	4	3700
	3	7.32	23	12.25	38.5	1575	6	4	3000
50	2	7.96	25	13.70	43	2150	6.5	4	3700
	3	7.32	23	12.70	40	1850	6.5	4	3000
55	1	8.59	27	15.11	47.5	2860	7	4.5	4500
	2	7.96	25	14.15	44.5	2475	7	4.5	3700
	3	7.32	23	13.20	41.5	2145	7	4.5	3000
60	1	8.59	27	15.75	49.5	3360	7	4.5	4500
	2	7.96	25	14.62	46	2820	7	4.5	3700
65	1	8.59	27	16.20	51	3835	7.5	5	4500
	2	7.96	25	15.11	47.5	3250	7.5	5	3700
70	1	8.59	27	16.70	52.5	4340	7.5	5	4500
	2	7.96	25	15.60	49	3640	7.5	5	3700
75	1	8.59	27	17.20	54	4800	8	5.5	4500
	2	7.96	25	16.05	50.5	4050	8	5.5	3700
80	1	8.59	27	17.50	55	5240	8	6	4500
	2	7.96	25	16.40	51.5	4400	8	6	3700
85	1	8.59	27	18.00	56.5	5780	8.5	6.5	4500
	2	7.96	25	16.88	53	4930	8.5	6.5	3700
90	1	8.59	27	18.30	57.5	6300	8.5	6.5	4500
	2	7.96	25	17.20	54	5400	8.5	6.5	3700

NOTE:
The ultimate fiber stress for creosoted Southern Yellow Pine & Douglas Fir is 7,400 Lbs. per square inch.
Weights are for untreated poles. Add 5% as estimate of added weight of creosote treatment.




REFERENCES:
American Standards Association 05.4-1941, 05.6-1945.
Standard Handbook for Electrical Engineers, Eighth Edition
H. E. Co. Specification for Poles.

WOOD POLE DATA

APPROVED:
P.D. Henderson 8-20-68
HAWAIIAN ELECTRIC Co., Inc. DATE
J.F. Judd 8-20-68
HAWAIIAN TELEPHONE Co. DATE

STATE OF HAWAII
DEPARTMENT OF TRANSPORTATION
HIGHWAYS DIVISION
STANDARD DETAILS
H.E. Co. AND H.T. Co.
SERVICE BOX DETAILS
AND WOOD POLE DATA
Scales: As Noted Date: 8/10/68

SHEET NO. 21 OF 27 SHEETS.

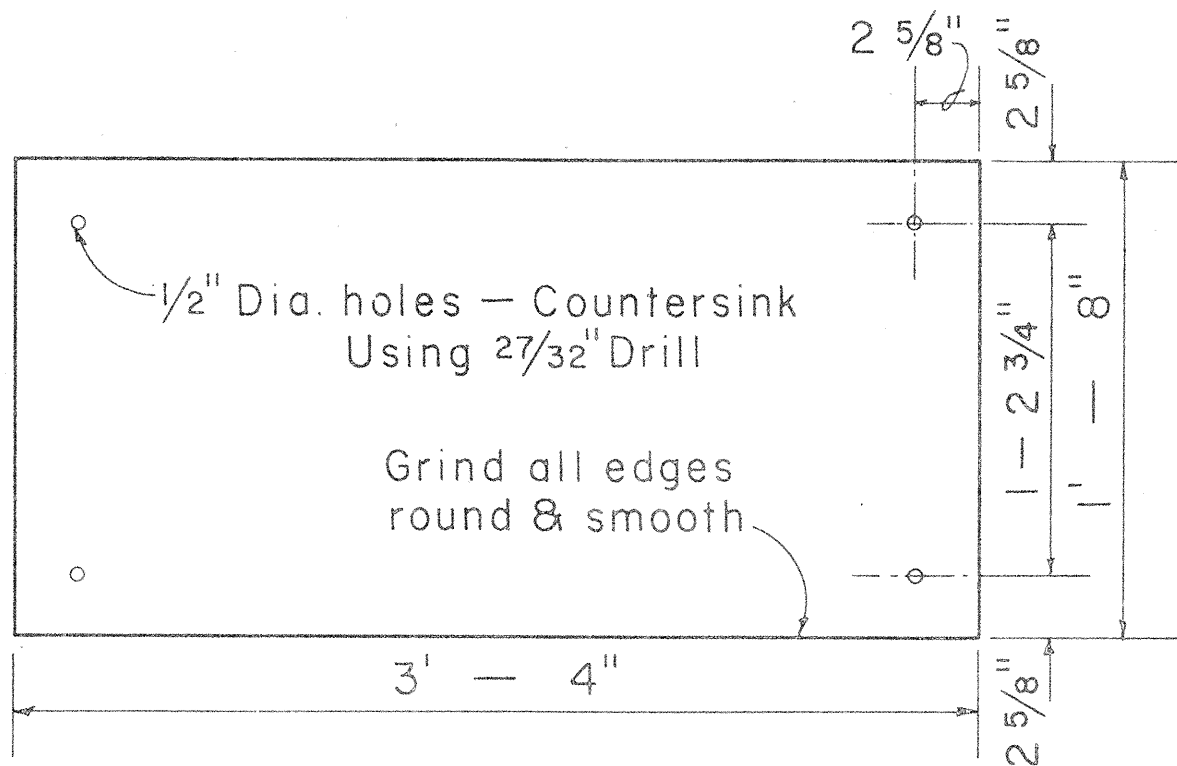
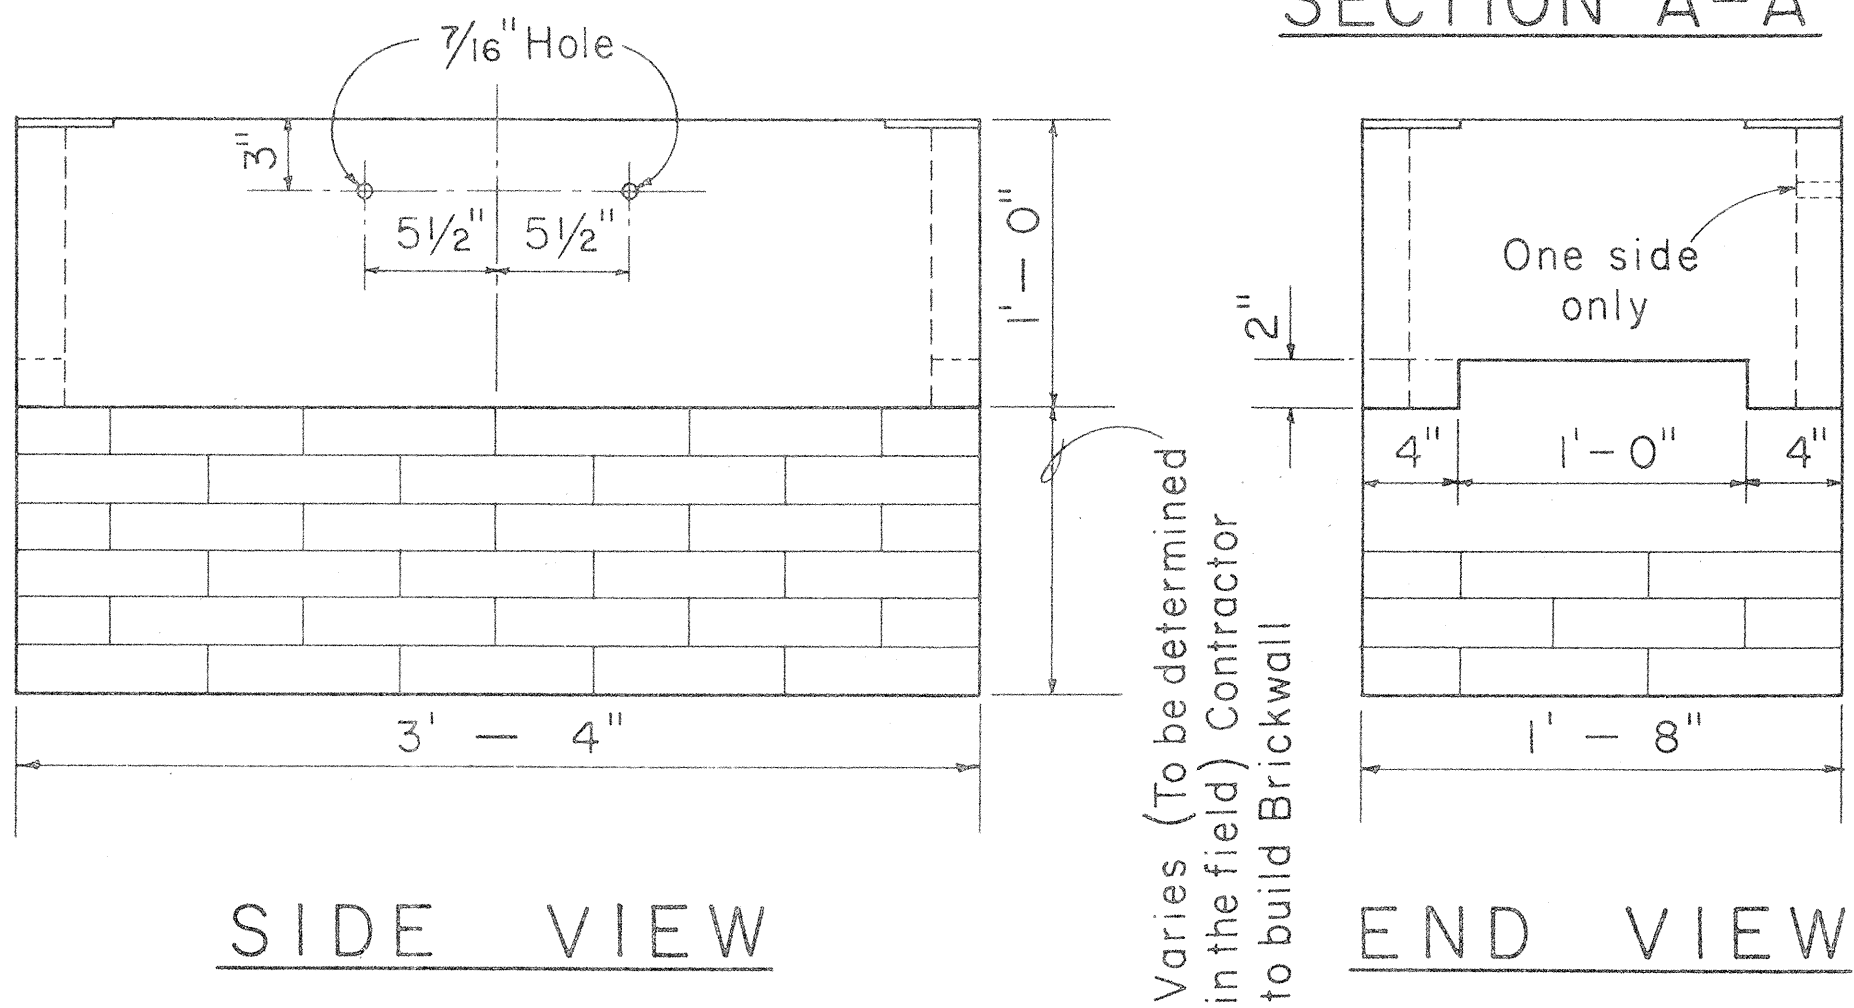
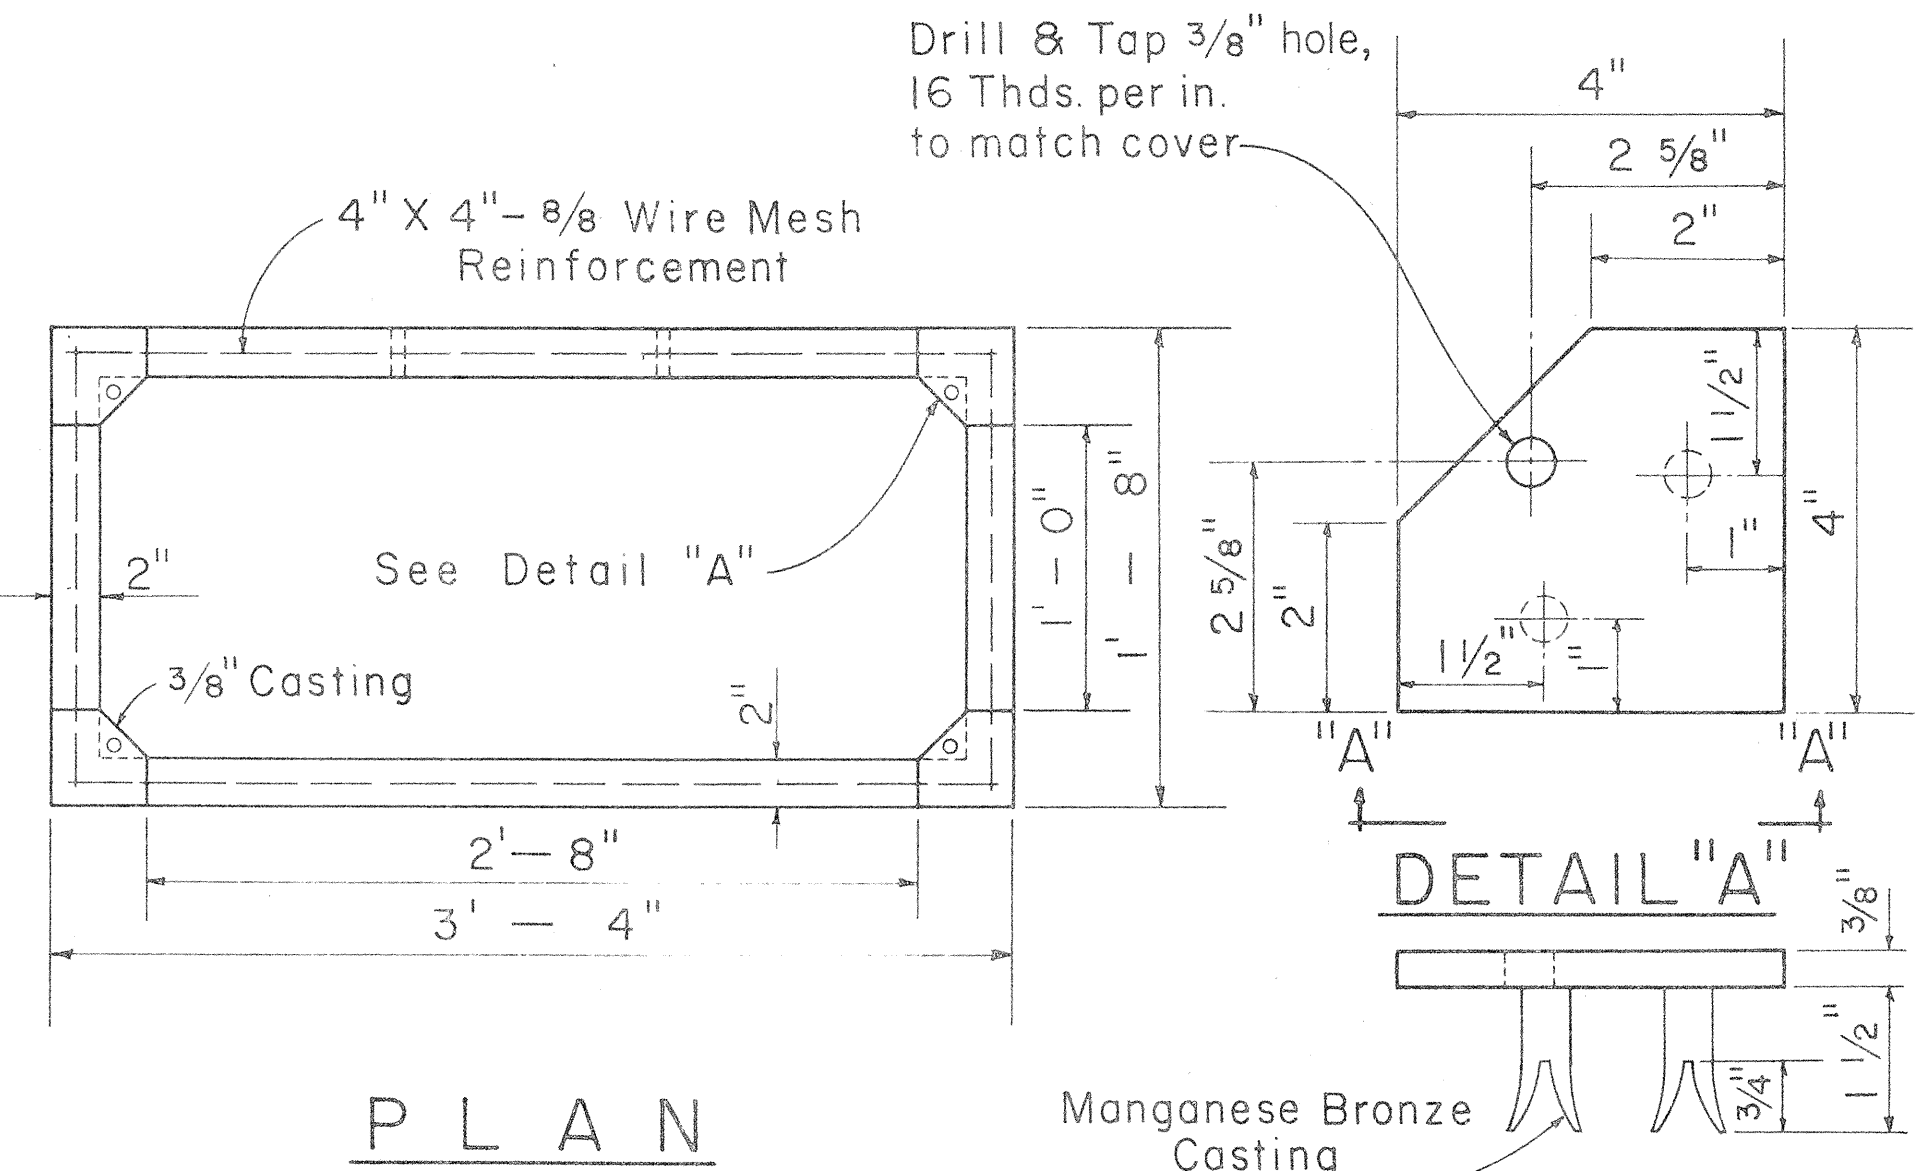


1/4" CHECKER PLATE COVER
(Hot dip galvanize checkered plate after drilling, countersinking, and grinding edge)

1'-4" X 3'-0" CONCRETE
SERVICE BOX

Scale: 1 1/2" = 1'-0"

011250

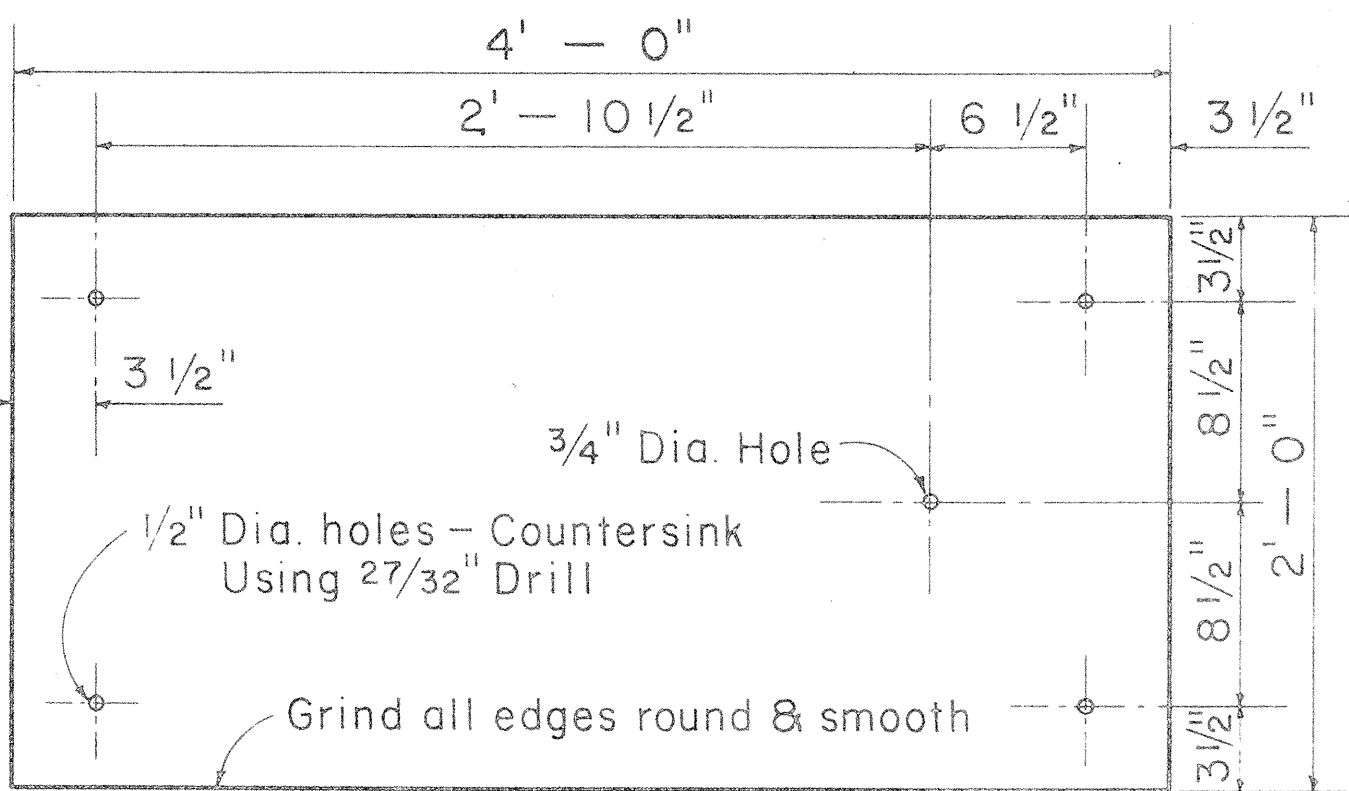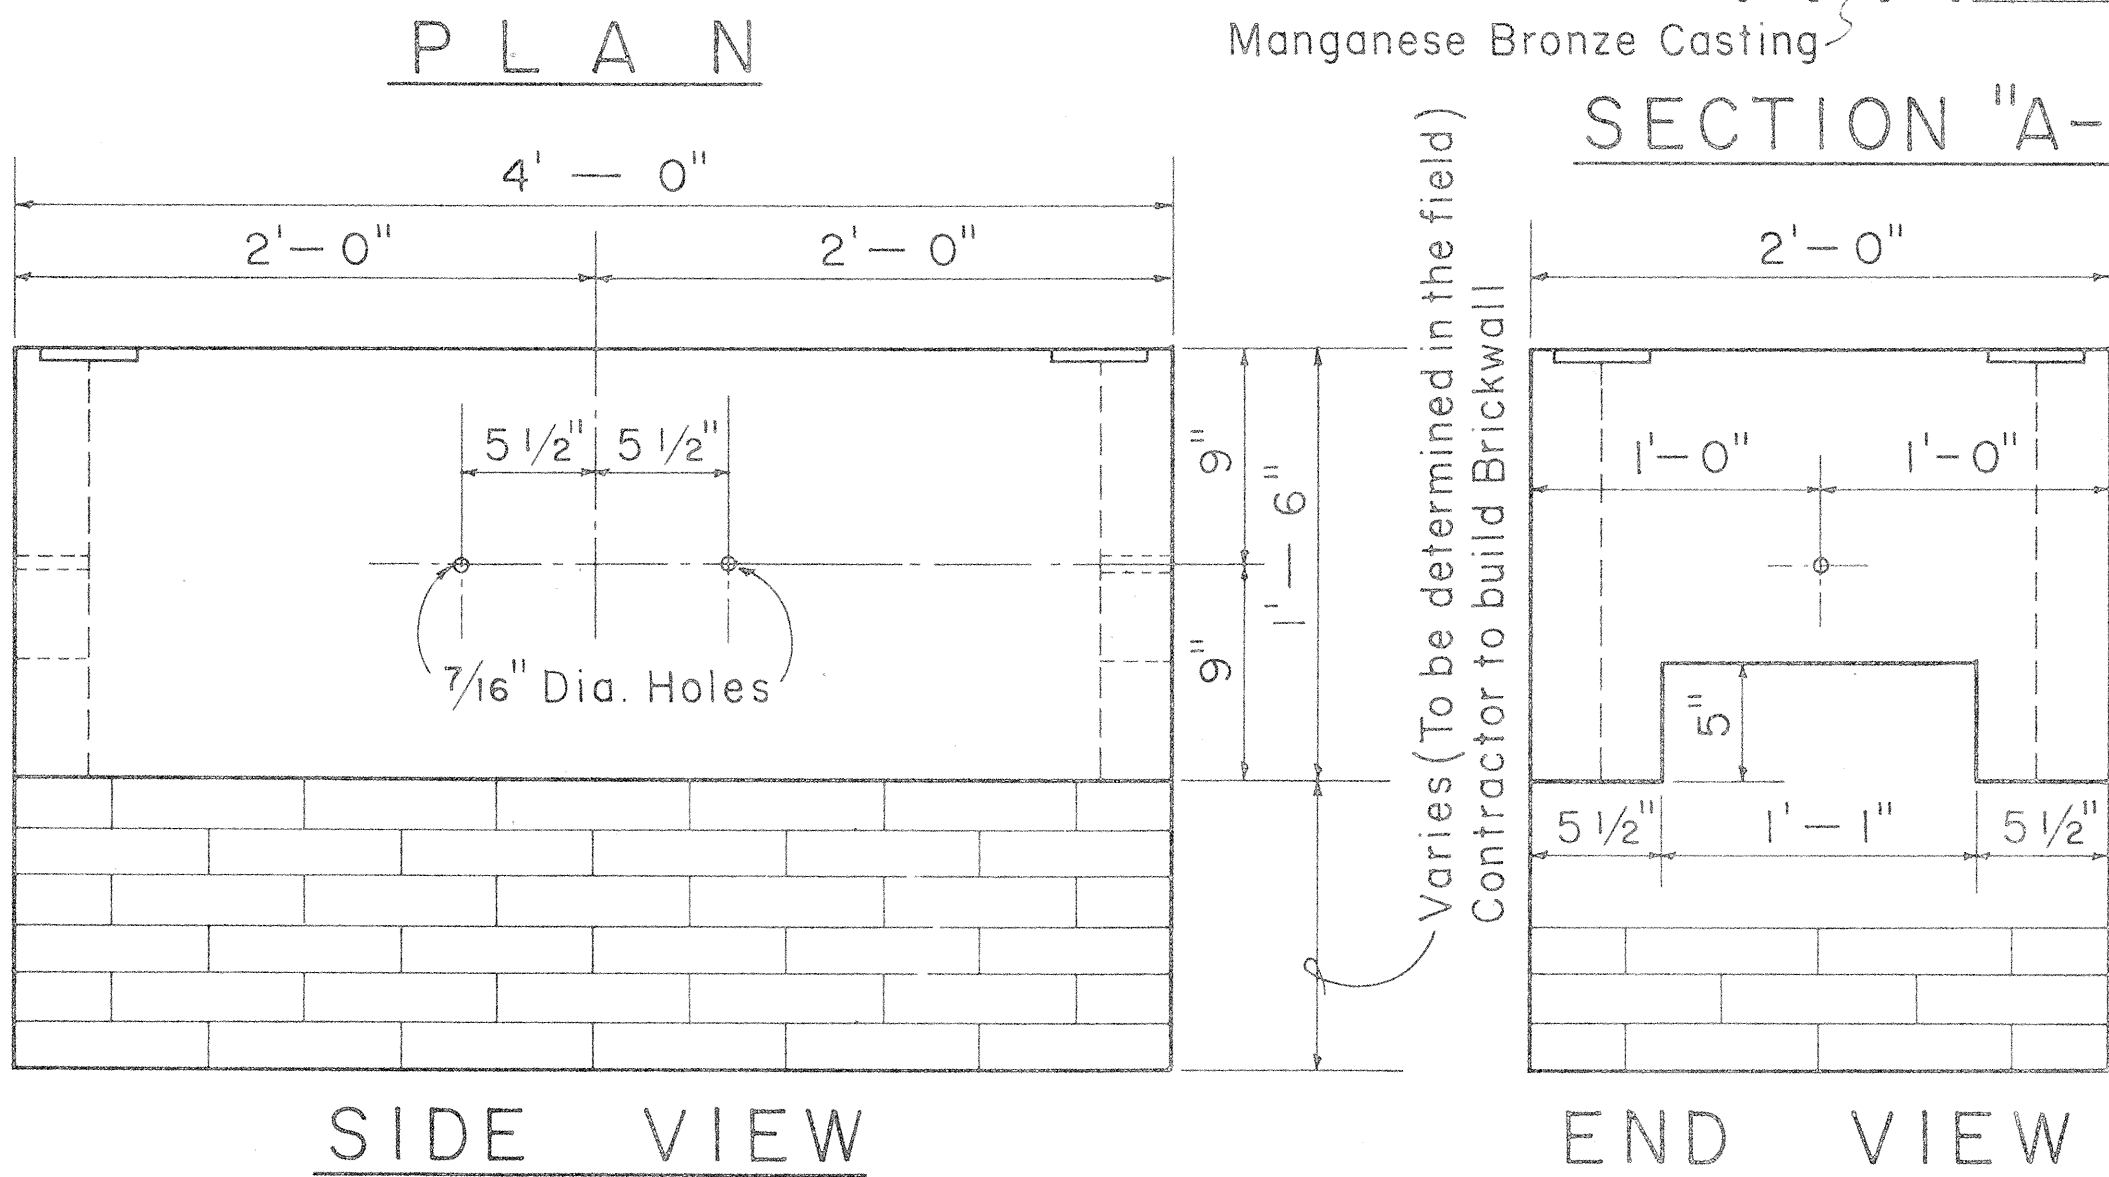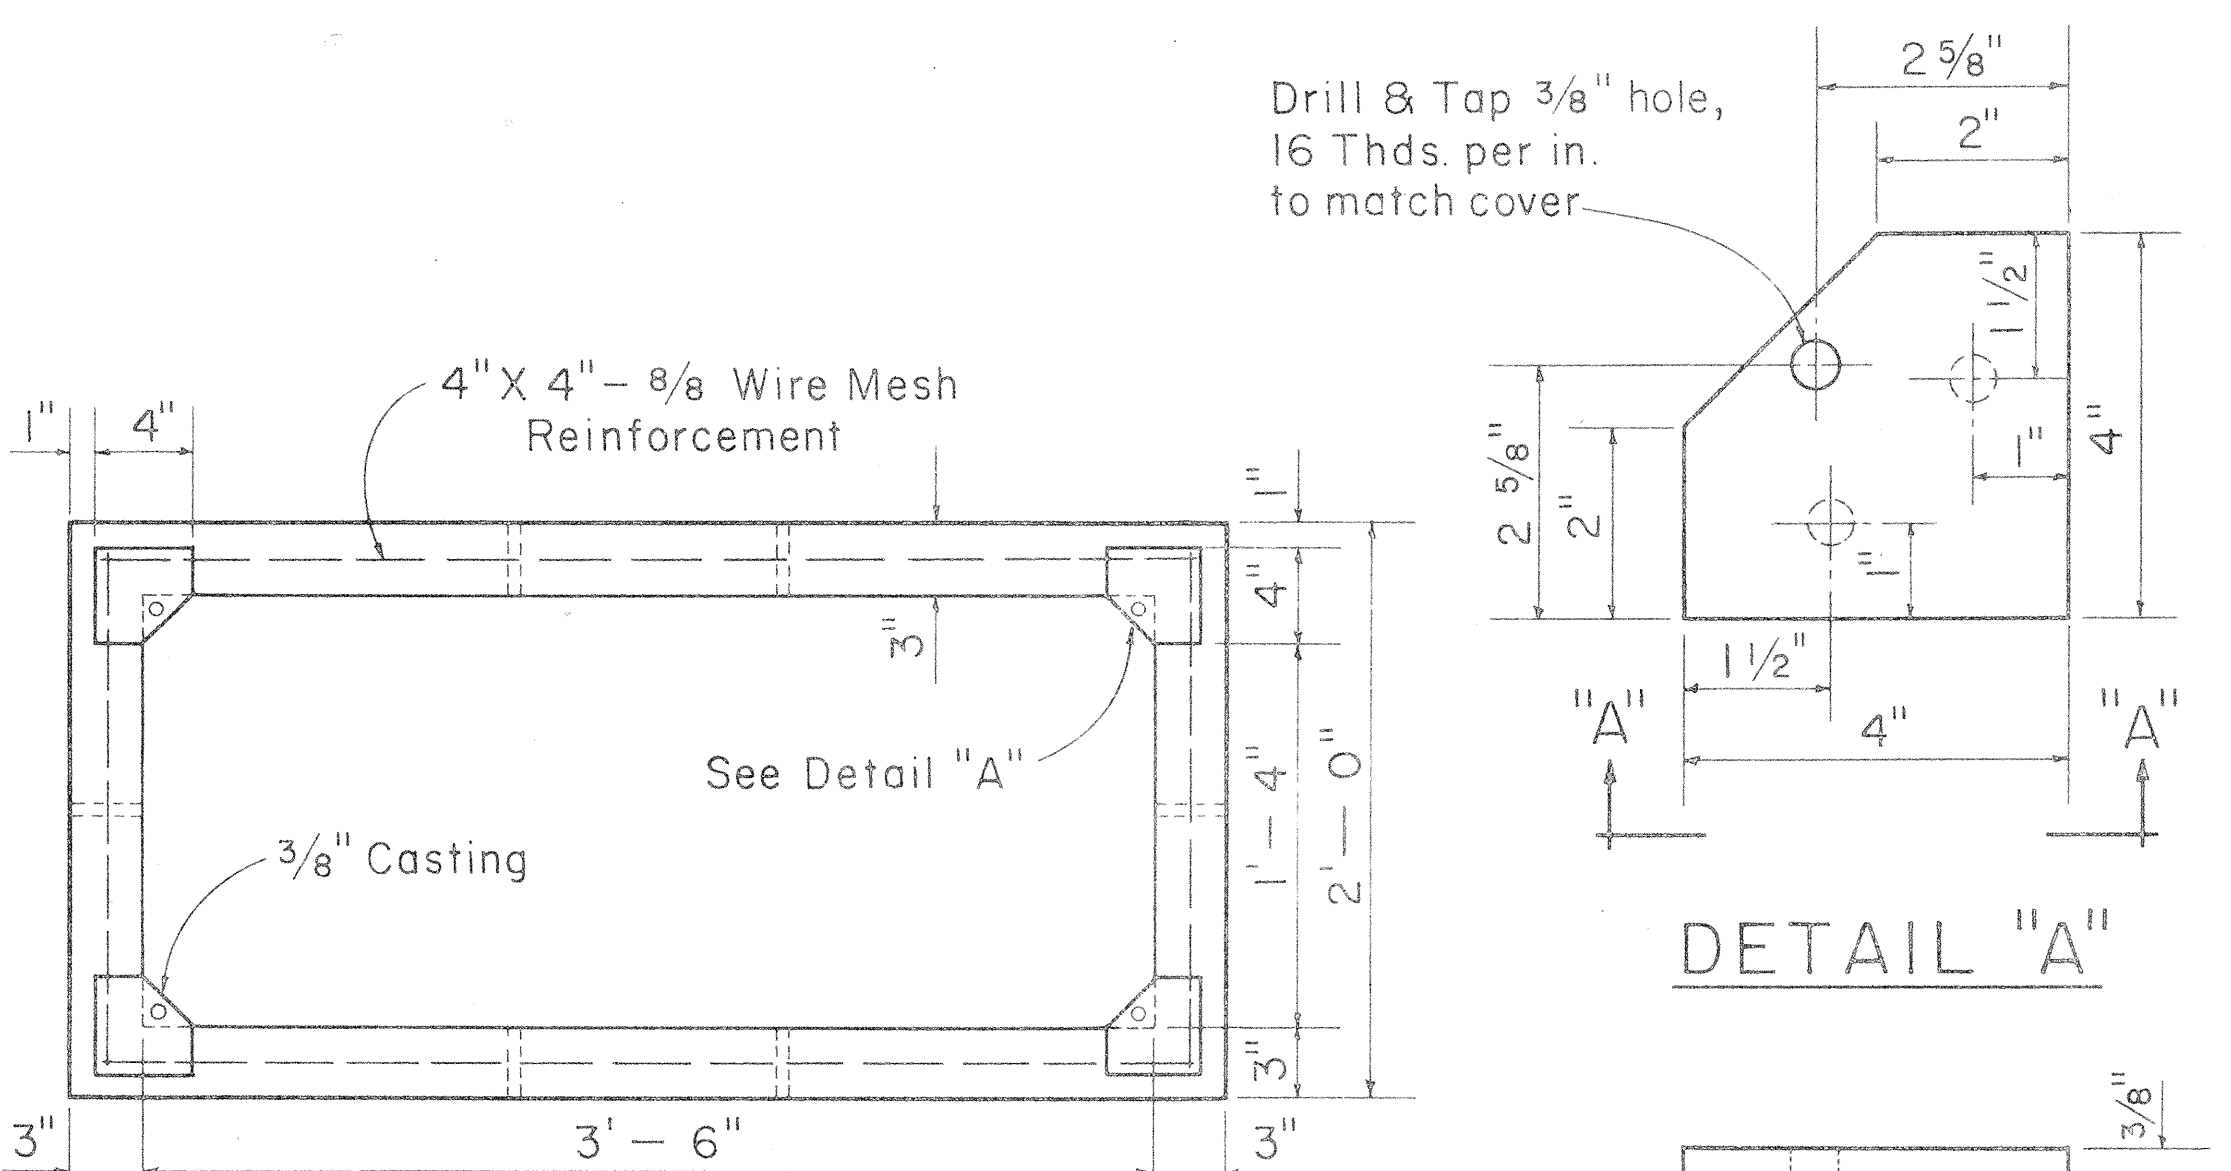


1/4" CHECKER PLATE COVER
(Hot dip galvanize checkered plate after drilling, countersinking, and grinding edge)

1'-6" X 3'-6" CONCRETE
SERVICE BOX

Scale: 1 1/2" = 1'-0"


011255

ORIGINAL PLAN	DATE
SURVEY PLOTTED BY	
DRAWN BY	
DESIGNED BY	
QUANTITIES BY	
CHECKED BY	

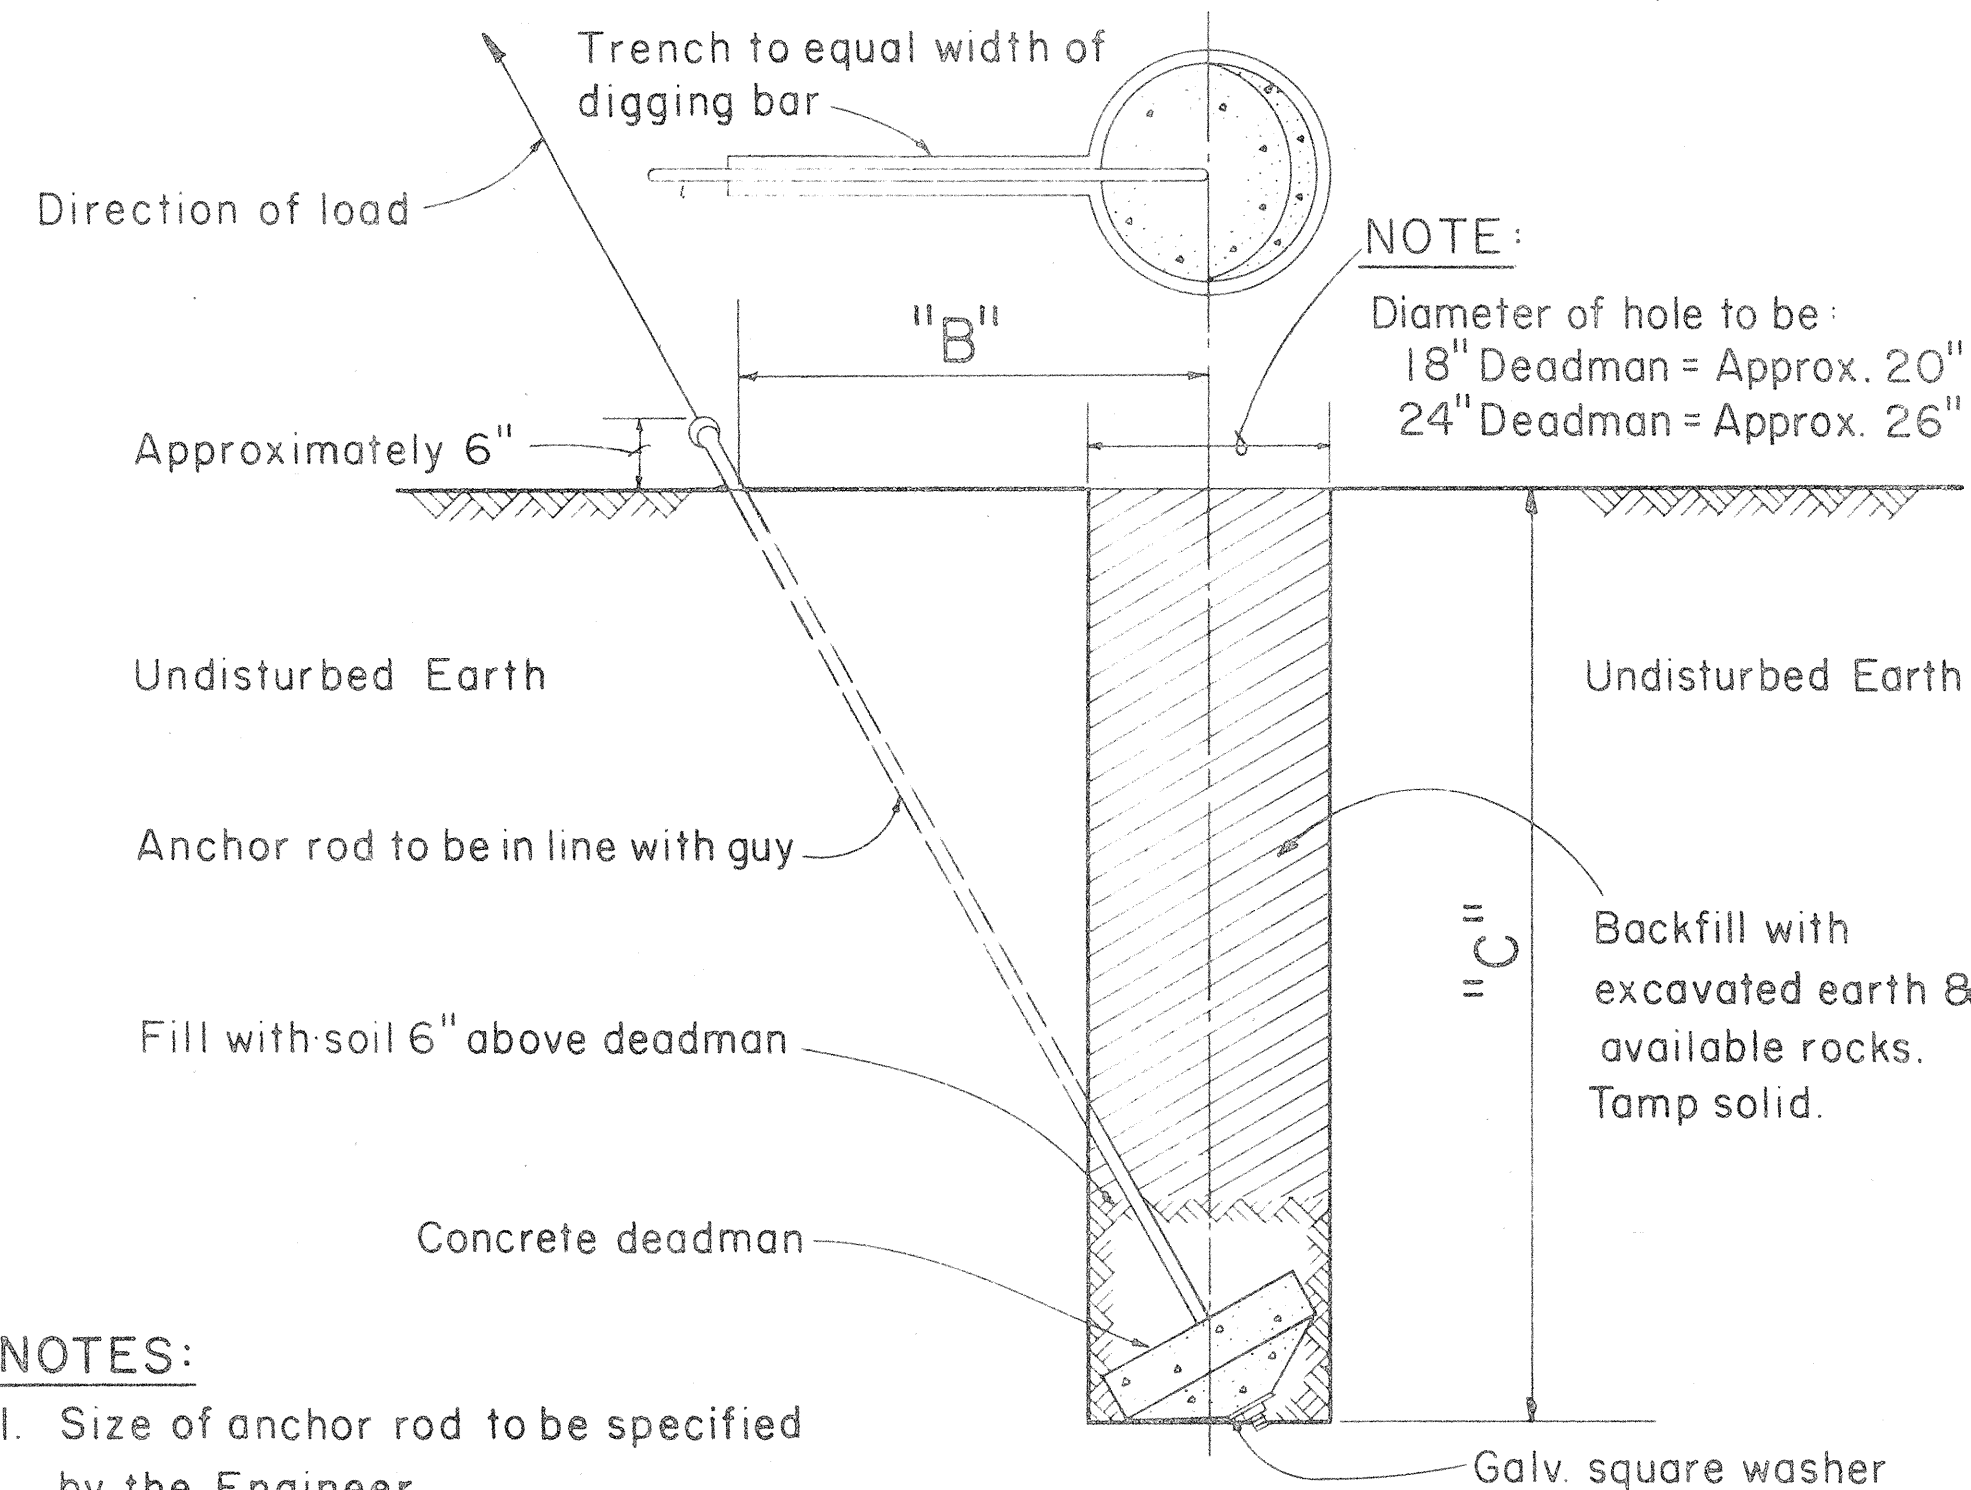


- NOTES:
1. Size of anchor rod to be specified by the Engineer
 2. Use Anchoring Data.

GUY ANCHOR DEADMAN
Scale: 3/4" = 1' - 0"

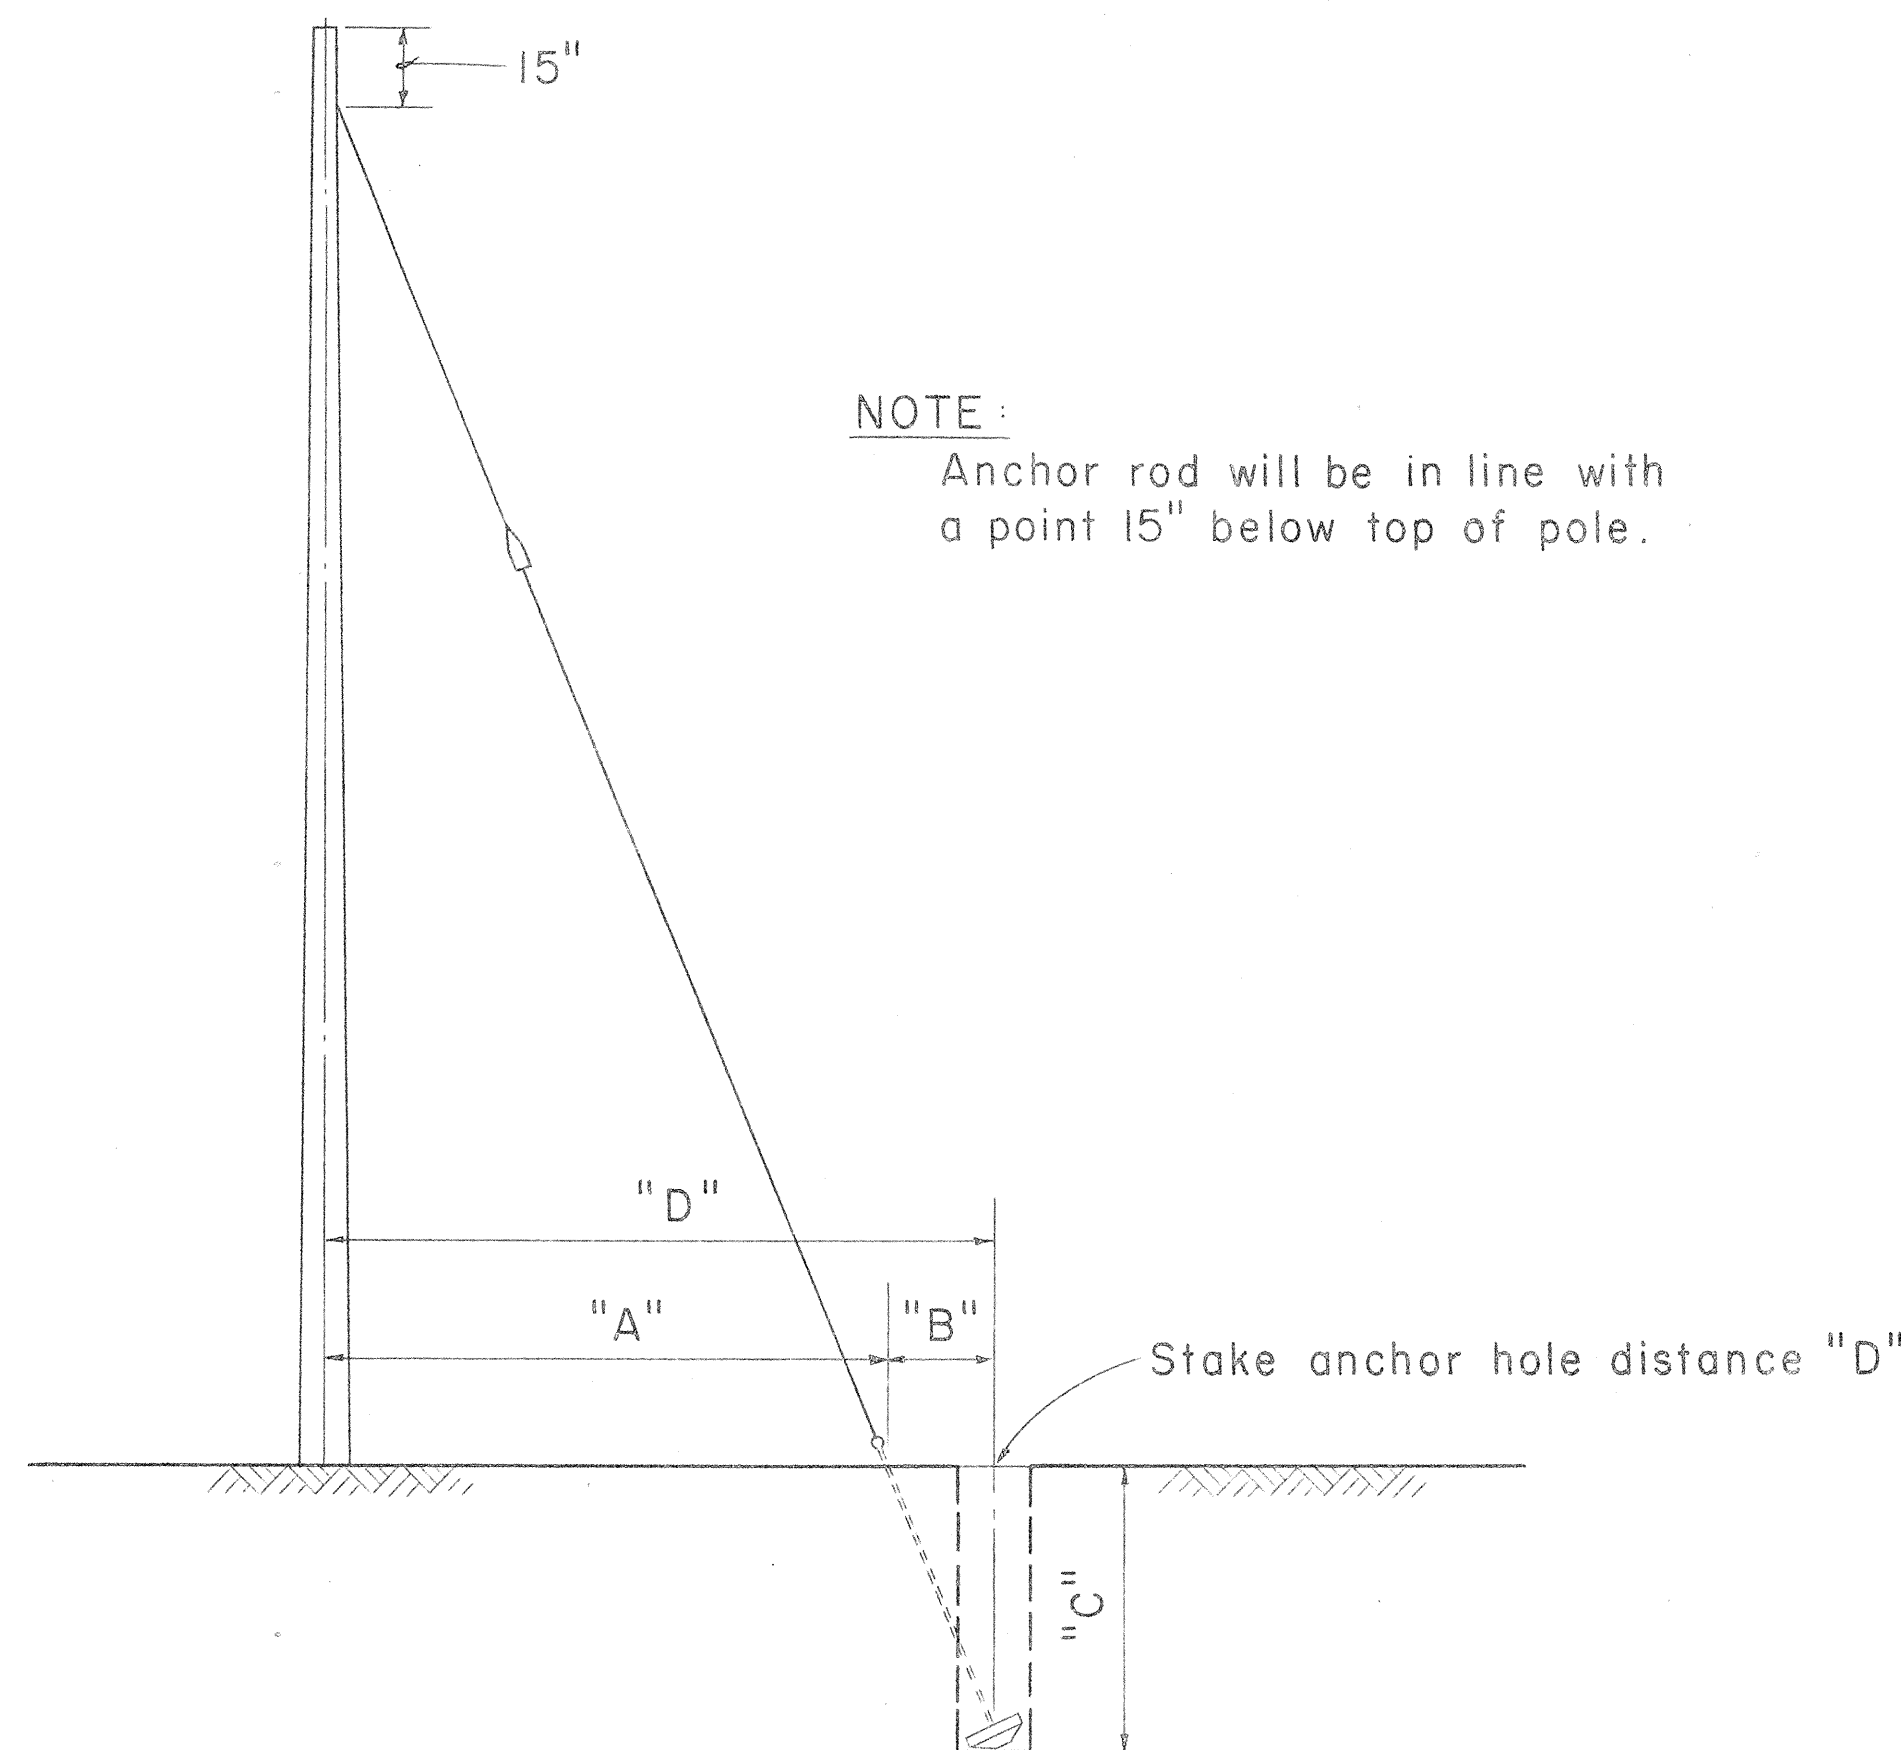


Not to Scale

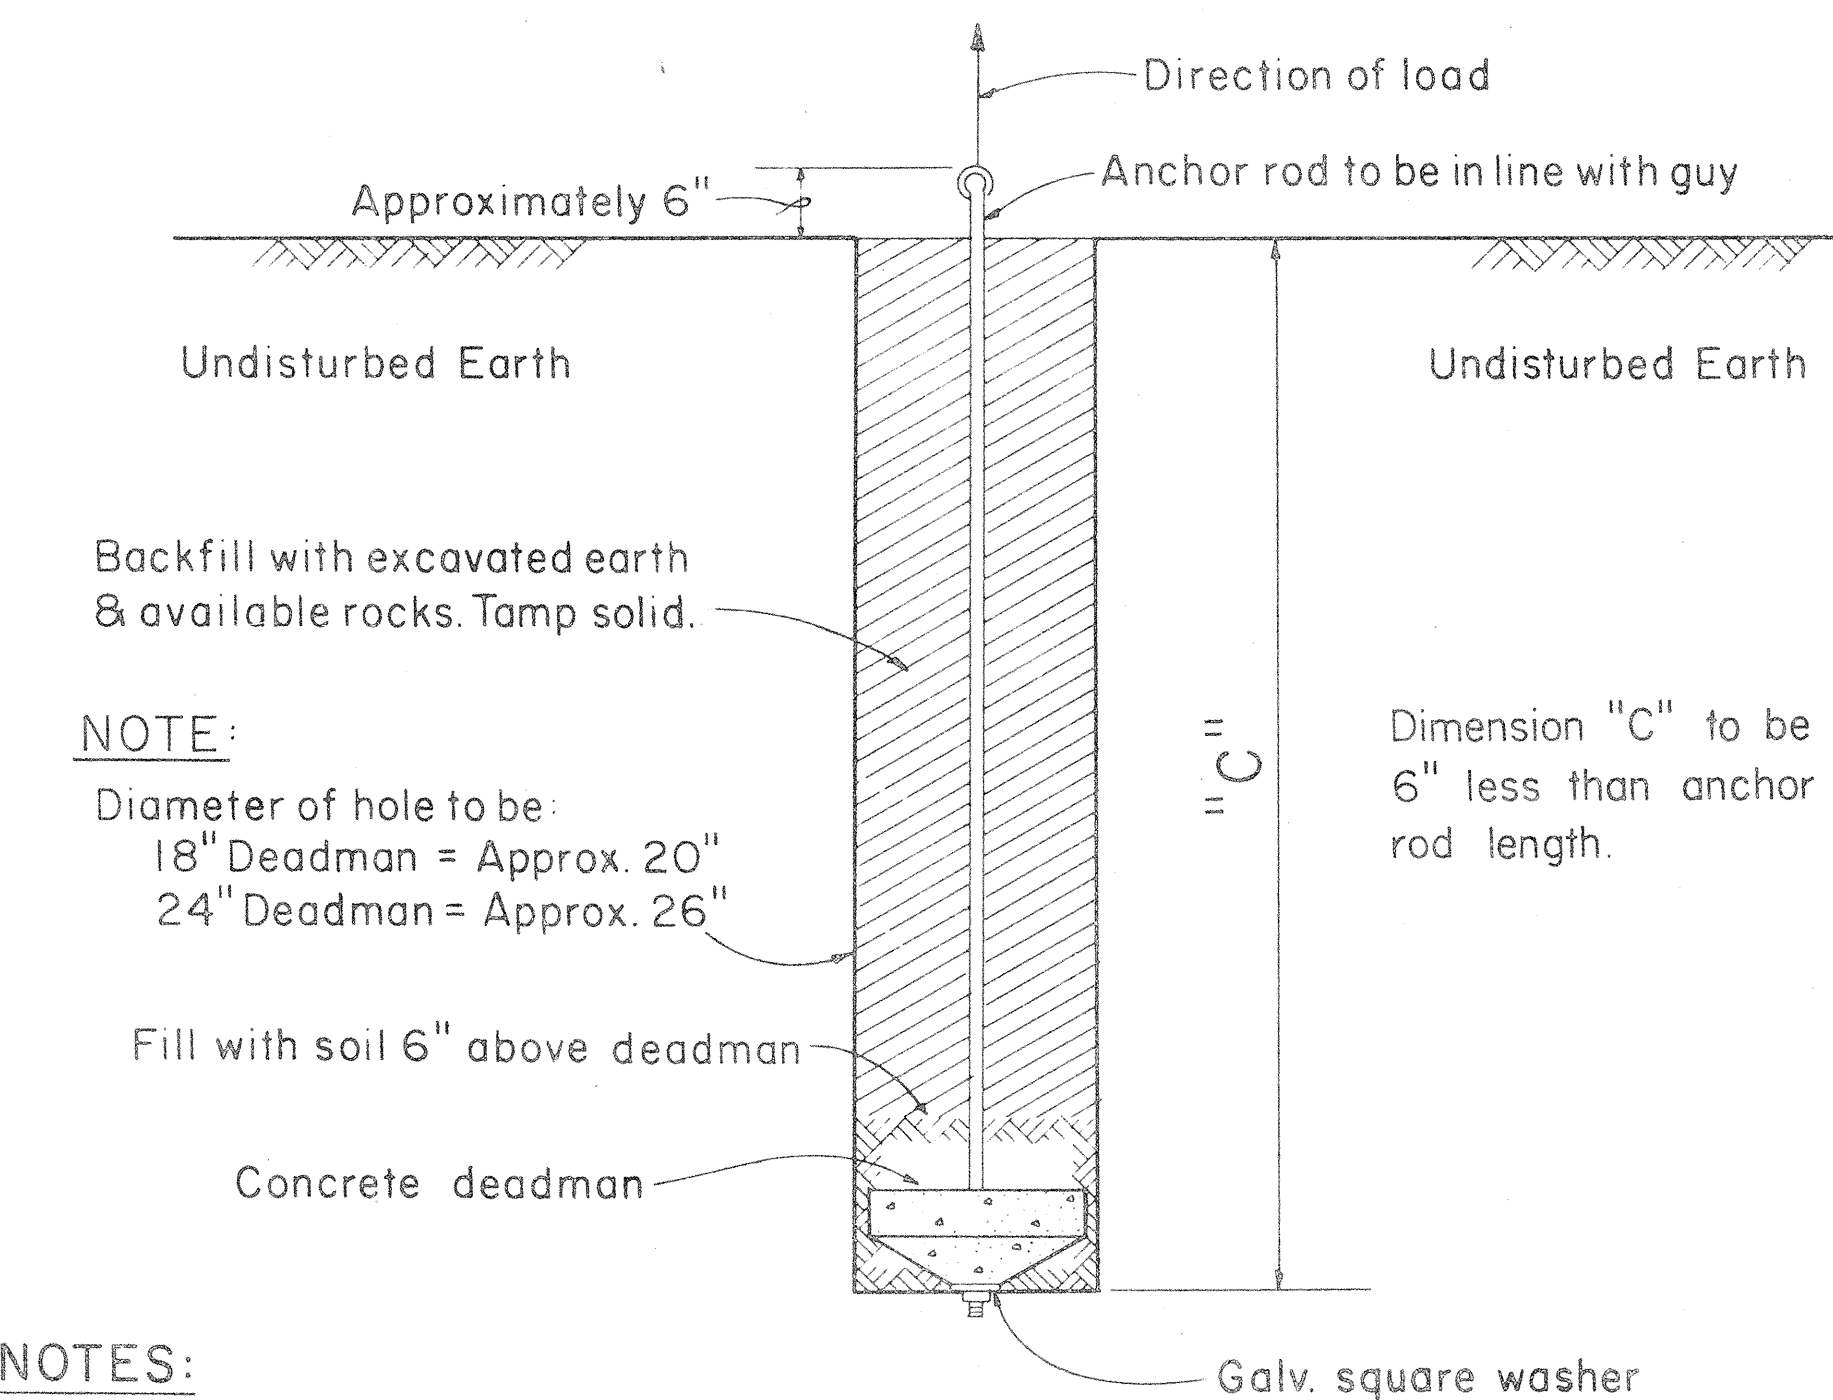

- NOTES:
1. Size of anchor rod to be specified by the Engineer.
 2. Use Anchoring Data.

SIDE - WALK ANCHOR
Scale: 3/4" = 1' - 0"

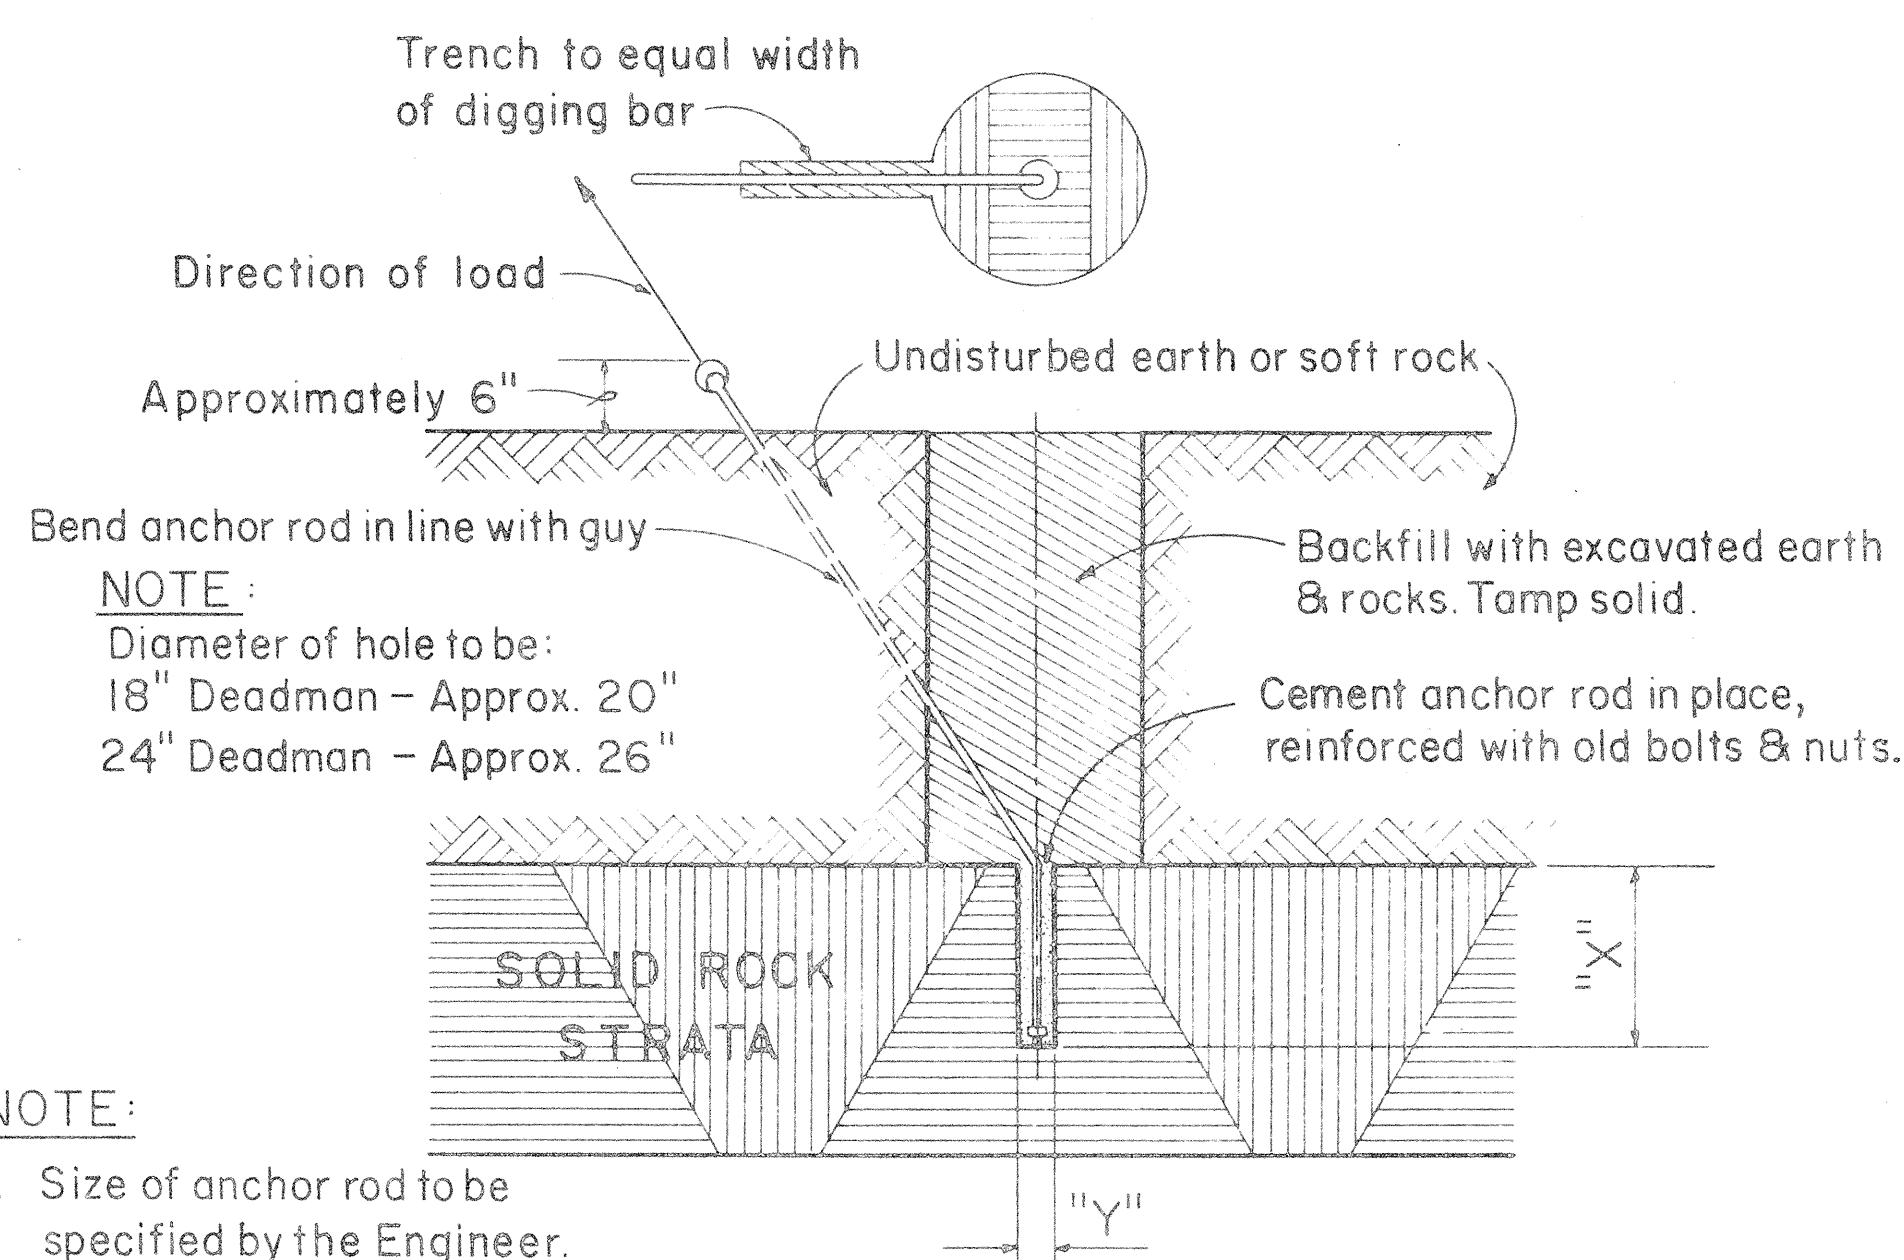

- NOTE:
1. Size of anchor rod to be specified by the Engineer.
 2. "X" Should not be less than 24". If "X" is less than 24" complete hole & install anchor.
 3. "Y" 5/8" Anchor rod drill 2" hole
3/4" Anchor rod drill 2" hole
1" Anchor rod drill 2 1/2" hole
1 1/4" Anchor rod drill 3" hole
 4. Use Anchoring Data.

ROCK ANCHOR
Not to Scale

FOR 25', & 30' POLES WITH 8'-0" ANCHOR RODS				
"A"	"B"	"C"	"D" = ("A" + "B")	
LEAD-ANCHOR ROD TO C.O.F. POLE	ANCHOR ROD TO C.O.F. HOLE	VERTICAL DEPTH	TOTAL DISTANCE POLE TO HOLE	
18" D.M.	24" D.M.			
5'-0"	1'-8"	7'-1"	7'-4"	6'-8"
10'-0"	3'-0"	6'-7"	7'-0"	13'-0"
15'-0"	4'-0"	6'-1"	6'-6"	19'-0"
20'-0"	4'-8"	5'-6"	5'-10"	24'-8"
25'-0"	5'-2"	4'-11"	5'-4"	30'-2"

FOR 35' THRU 70' POLES WITH 8'-0" ANCHOR RODS				
5'-0"	1'-0"	7'-3"	7'-4"	6'-0"
10'-0"	1'-11"	7'-1"	7'-3"	11'-11"
15'-0"	2'-8"	6'-9"	7'-1"	17'-8"
20'-0"	3'-3"	6'-6"	6'-10"	23'-3"
25'-0"	3'-10"	6'-2"	6'-7"	28'-10"

FOR 40' THRU 70' POLES WITH 1 1/4" x 10'-0" ANCHOR RODS				
5'-0"	1'-7"		9'-4"	6'-7"
10'-0"	3'-0"		9'-0"	13'-0"
15'-0"	4'-2"		8'-6"	19'-2"
20'-0"	5'-3"		7'-11"	25'-3"
25'-0"	6'-2"		7'-3"	31'-2"

D. M. = Deadman

TABLE 2 ANCHOR ROD - ANCHOR SLUG - SQUARE WASHER COMBINATION						
H.E. CODE NO.	ANCHOR ROD	WORKING TENSION 1/2 ULT (LBS.)	H.E. CONC. NO.	CONC. (IN.)	H.E. CODE NO.	WASHER SIZE
617	5/8" x 8'-0" Steel	8,000	518	18	2320	4" x 4" x 3/16"
615	5/8" x 8'-0" Cu Cov Stl	9,250	518	18	**	3" x 3" x 1/8"
618	3/4" x 8'-0" Steel	11,500	518	18	2330	6" x 6" x 3/8"
619	1" x 8'-0" Steel	18,000	524	24	2331	6" x 6" x 1/2"
616	1" x 8'-0" Cu Cov Stl	22,500	524	24	**	4" x 4" x 3/16"
613	1 1/4" x 10'-0" Steel	29,000	524	24	2330	6" x 6" x 3/8"

** Use bronze square washers included in anchor rod assembly on copper covered steel (Cu Cov Stl) anchor rods.

ANCHORING DATA

APPROVED:

W. Henderson 8-20-68
HAWAIIAN ELECTRIC Co., Inc. DATE


F. J. Judd 8-20-68
HAWAIIAN TELEPHONE Co. DATE

STATE OF HAWAII
DEPARTMENT OF TRANSPORTATION
HIGHWAYS DIVISION


STANDARD DETAILS
H.E. Co. AND H.T. Co.
ANCHOR DETAILS AND
ANCHORING DATA

Scales: As Noted Date: 8/19/68


FED. ROAD DIST. NO.	STATE	FED. AID PROJ. NO.	FISCAL YEAR	SHEET NO.	TOTAL SHEETS
HAWAII	HAW.	I-HI-1(64)-12 UNIT 2	1969	71	128
		I-HI-1(16)-11			

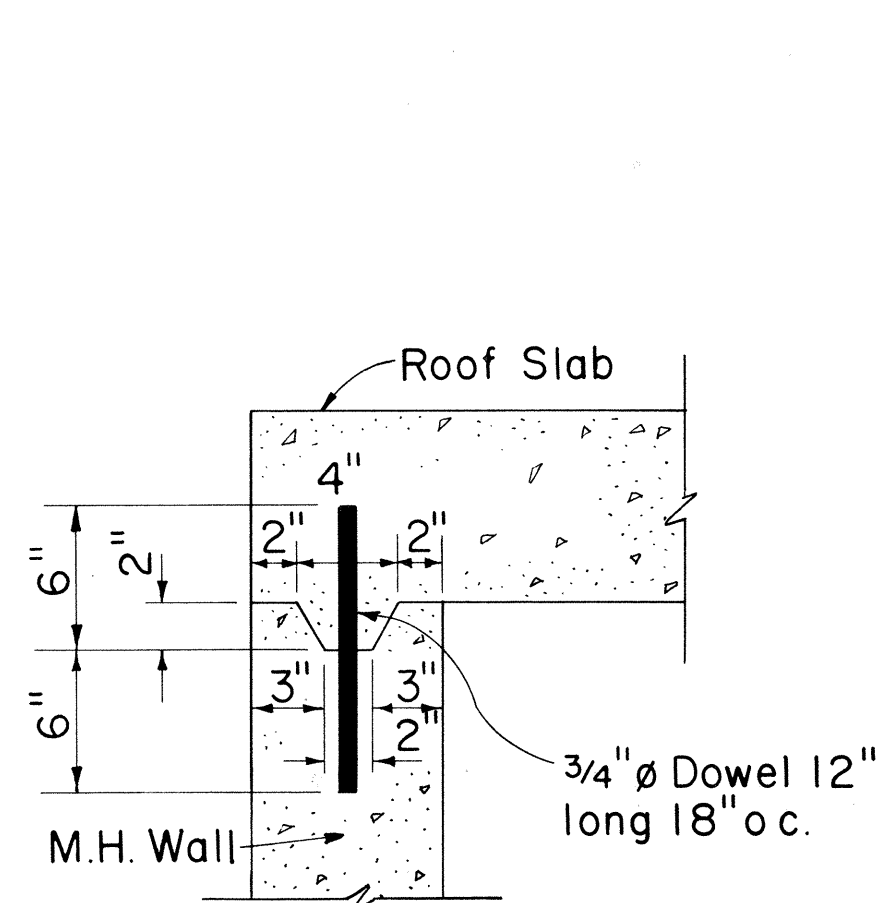


DETAIL "A"
TOP CONSTRUCTION JOINT
Scale: 1 1/2" = 1'-0"
(Optional for cast-in-place construction)
Required for precast construction

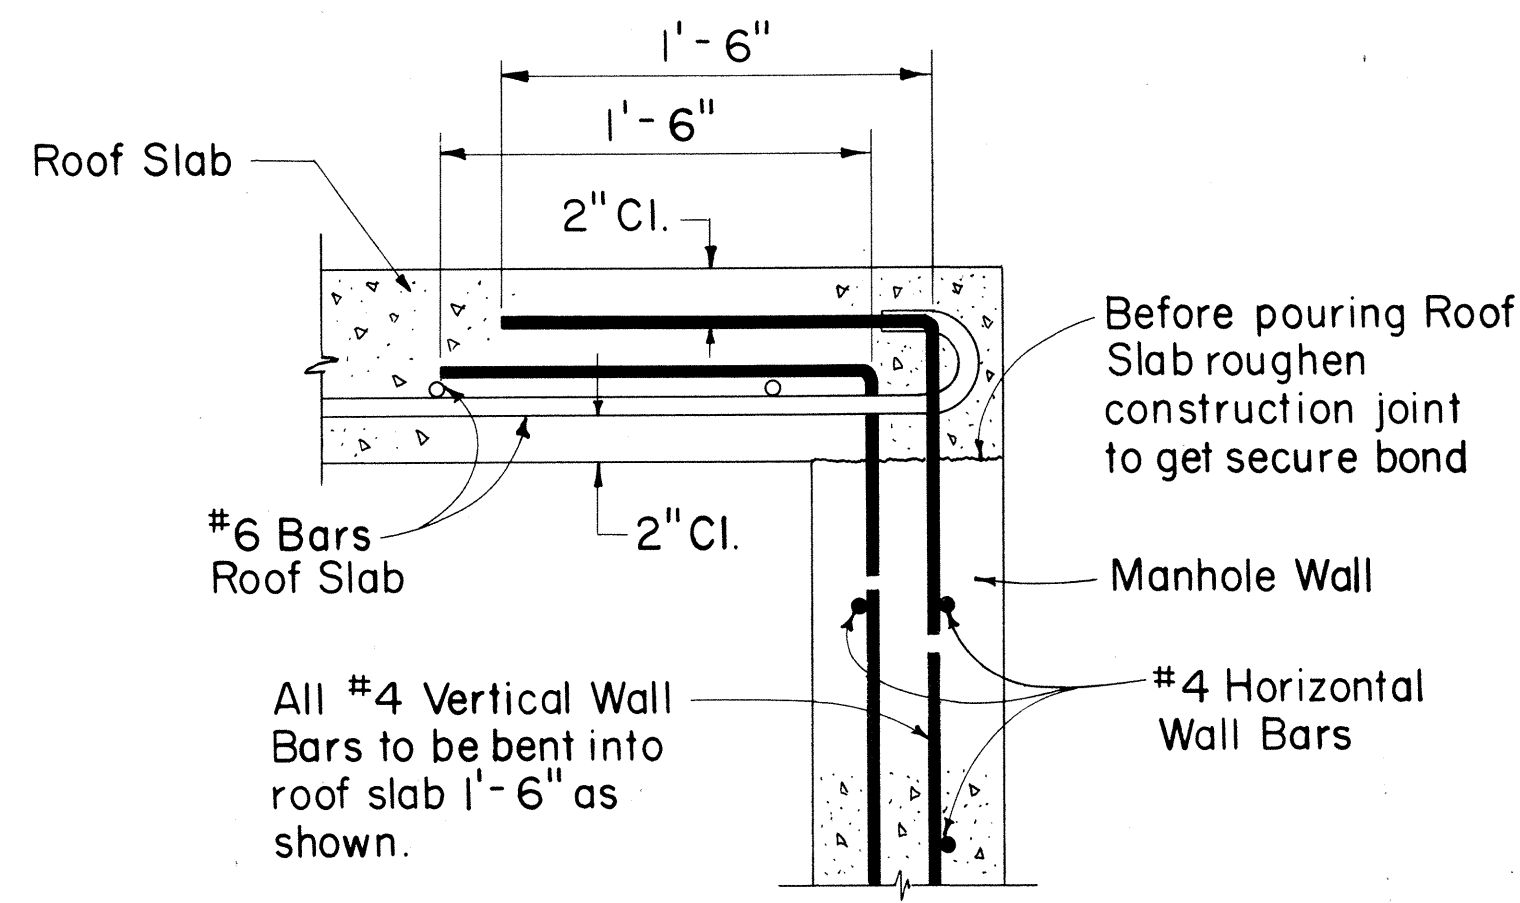


DETAIL "B"
(USED FOR CAST-IN-PLACE CONSTRUCTION)
Scale: 1 1/2" = 1'-0"

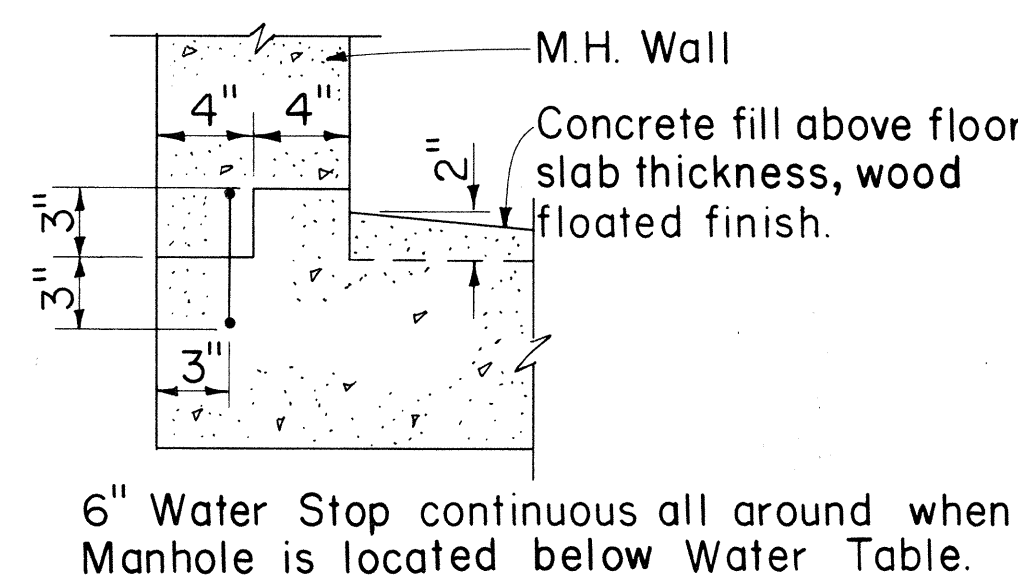


DETAIL "C"
BOTTOM CONSTRUCTION JOINT
Scale: 1 1/2" = 1'-0"

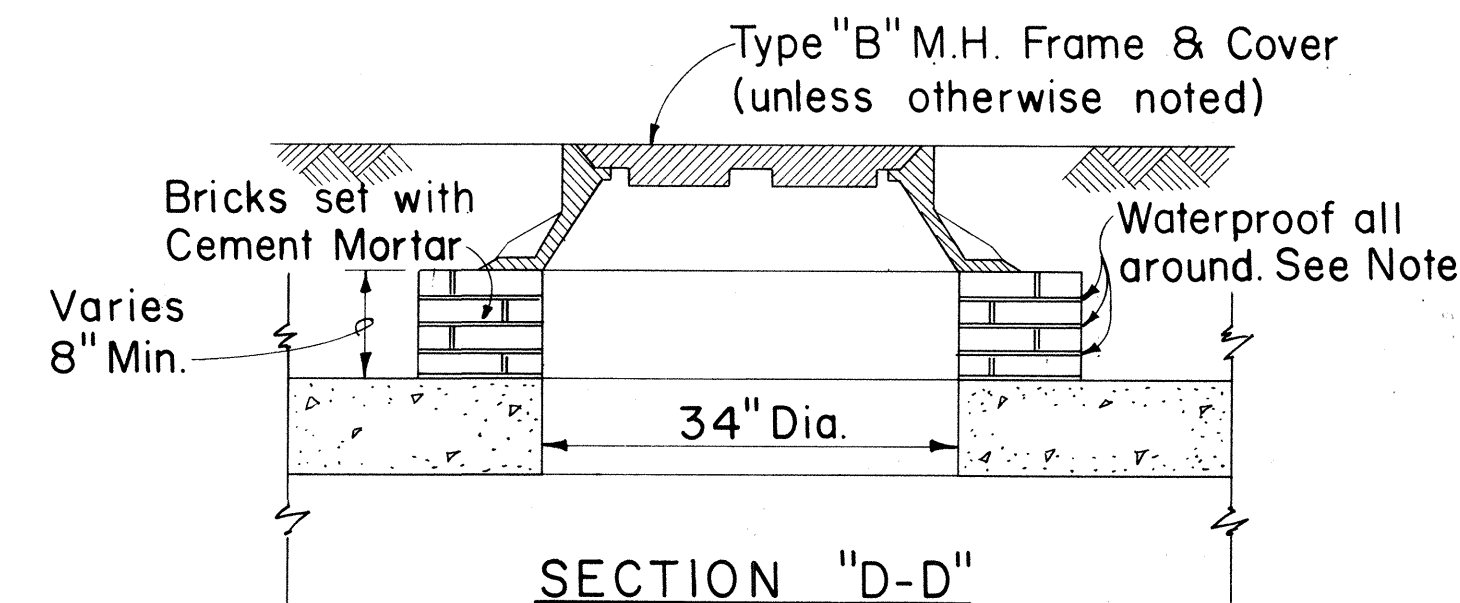


SECTION "D-D"
M.H. COVER DETAIL
Scale: 3/4" = 1'-0"

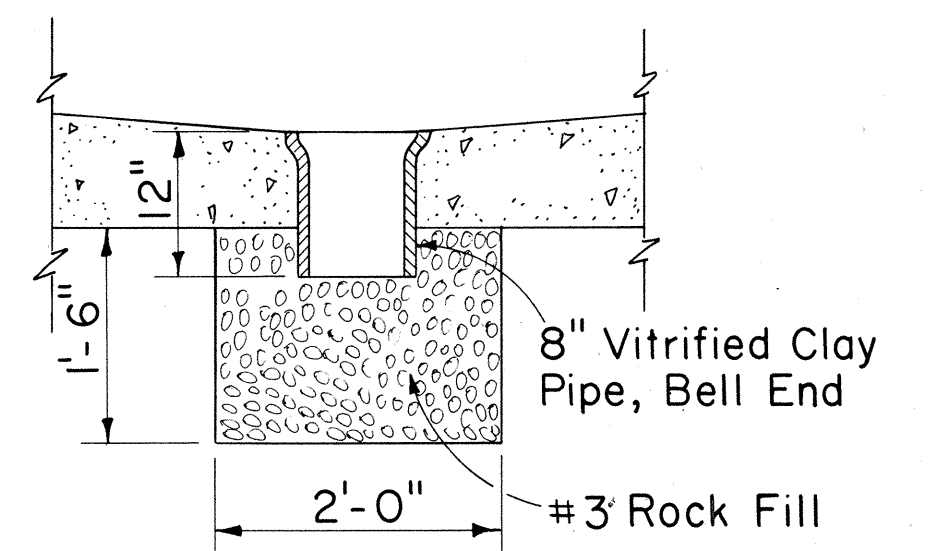


SECTION "E-E"
M.H. SUMP DETAIL
Scale: 3/4" = 1'-0"
Note:
See Section "E₁-E₁" Below

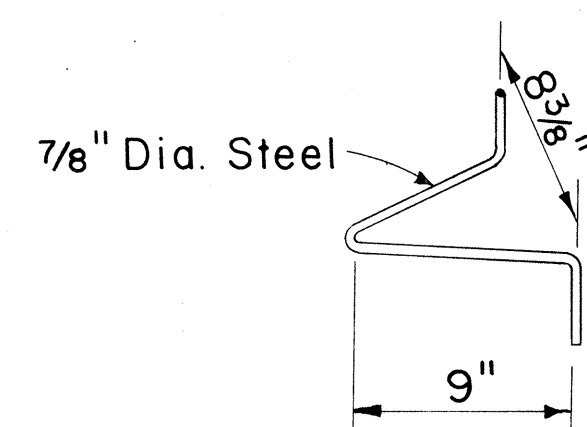


PULLING-IN IRON

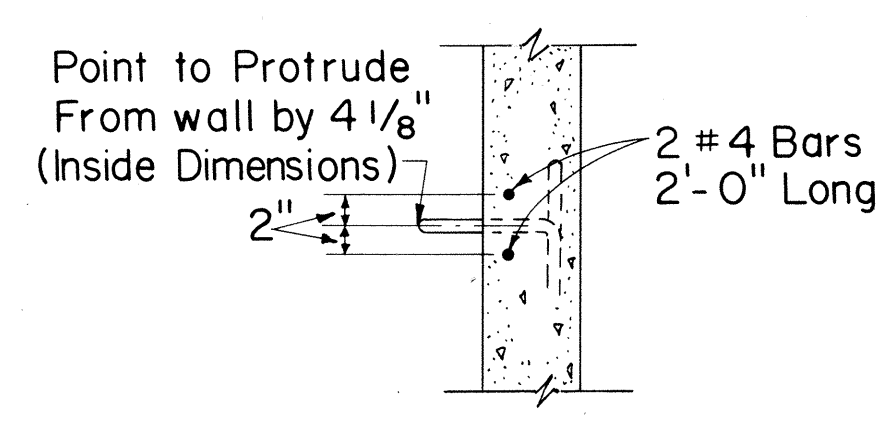


**SECTIONAL VIEW OF
PULLING-IN IRON**
Scale: 3/4" = 1'-0"

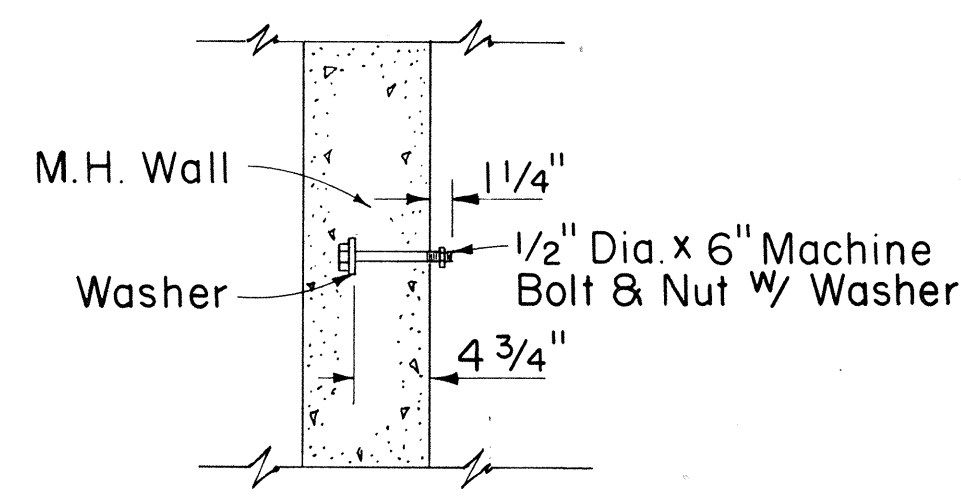

**CABLE RACK STUD
BOLT DETAIL**
Scale: 1" = 1'-0"

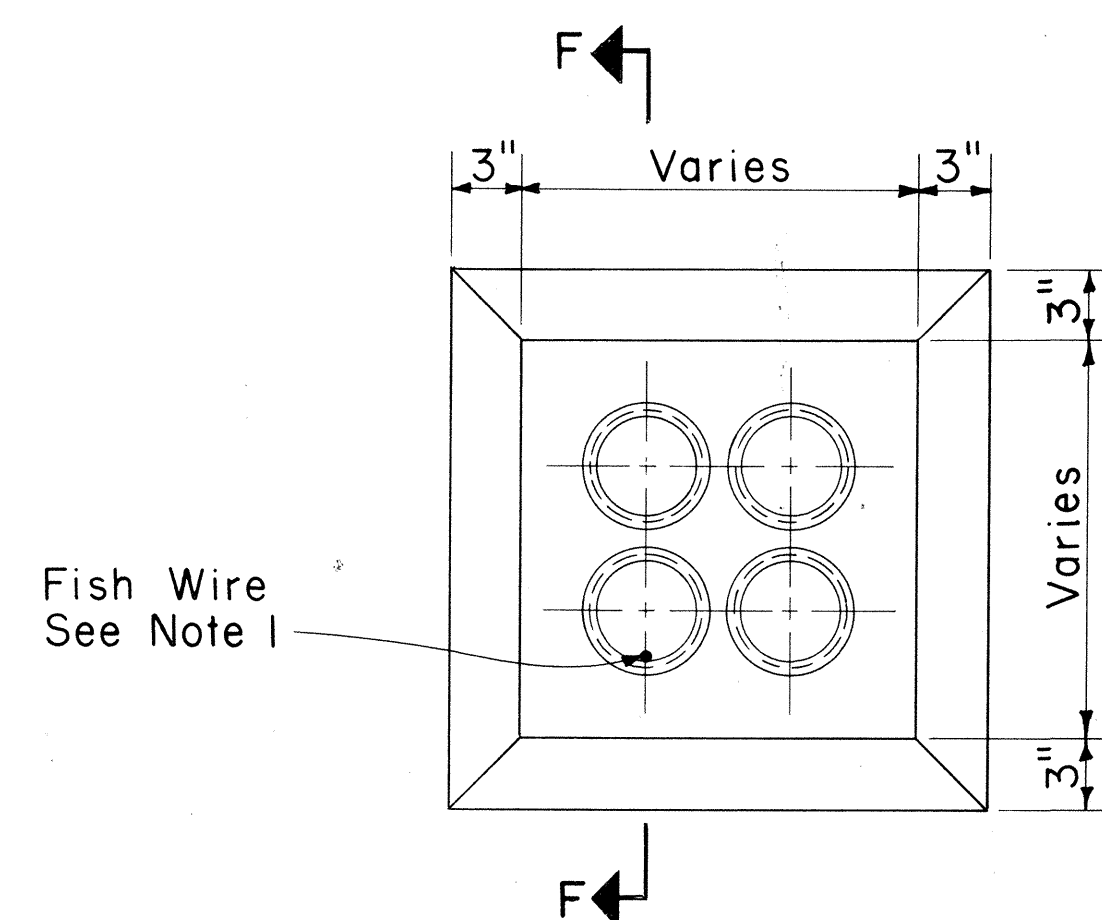


TYPICAL MANHOLE DUCT WINDOW
Scale: 1 1/2" = 1'-0"

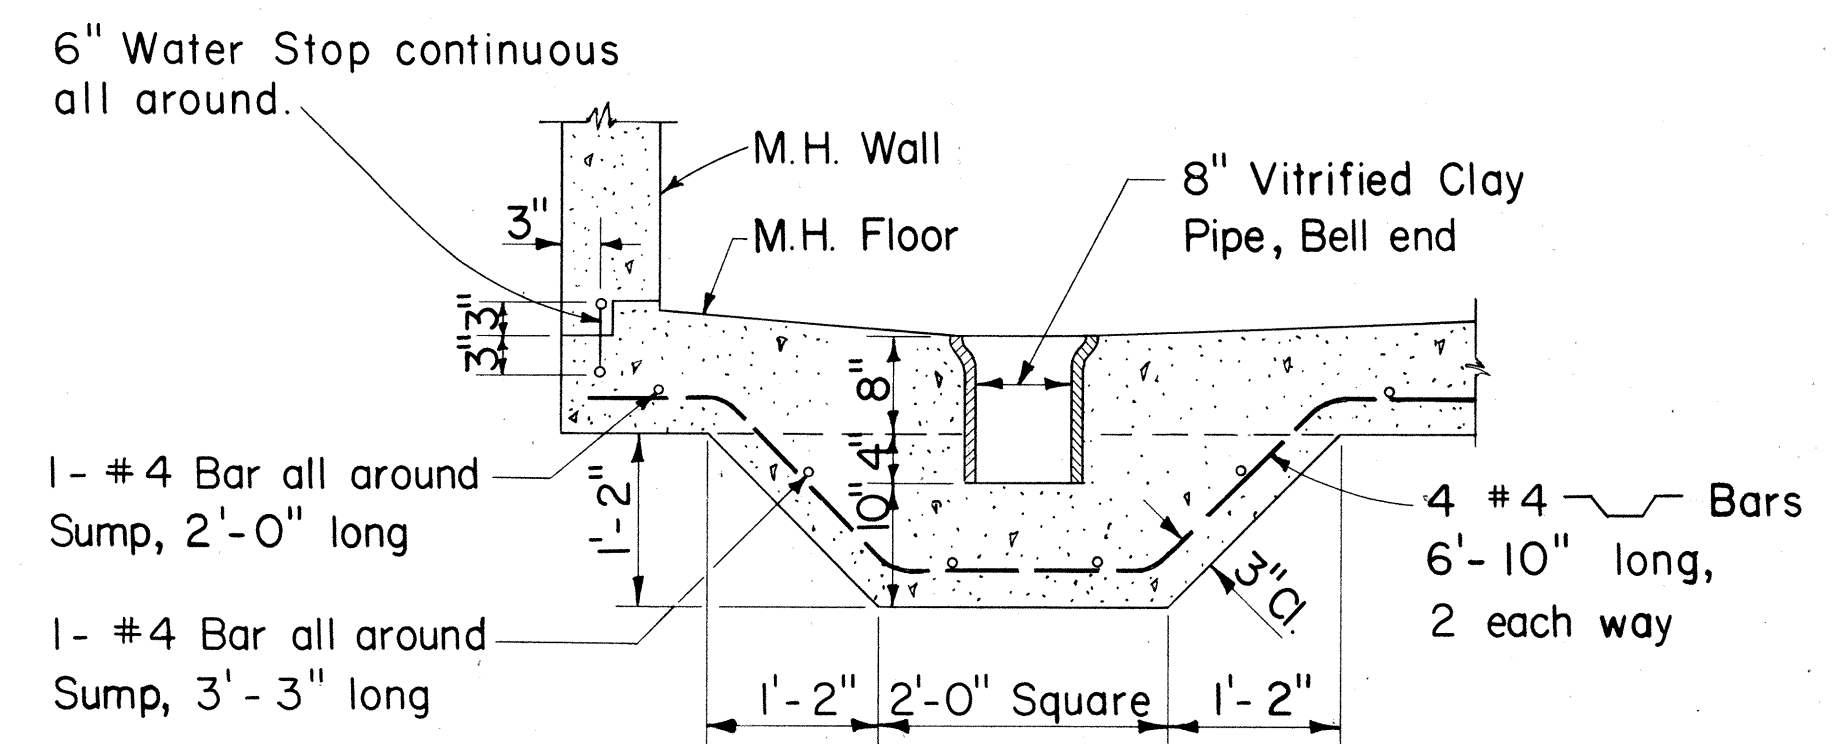


Note: Only for manholes located below water table


**SECTION "E₁-E₁"
MANHOLE SUMP DETAIL**
Scale: 3/4" = 1'-0"

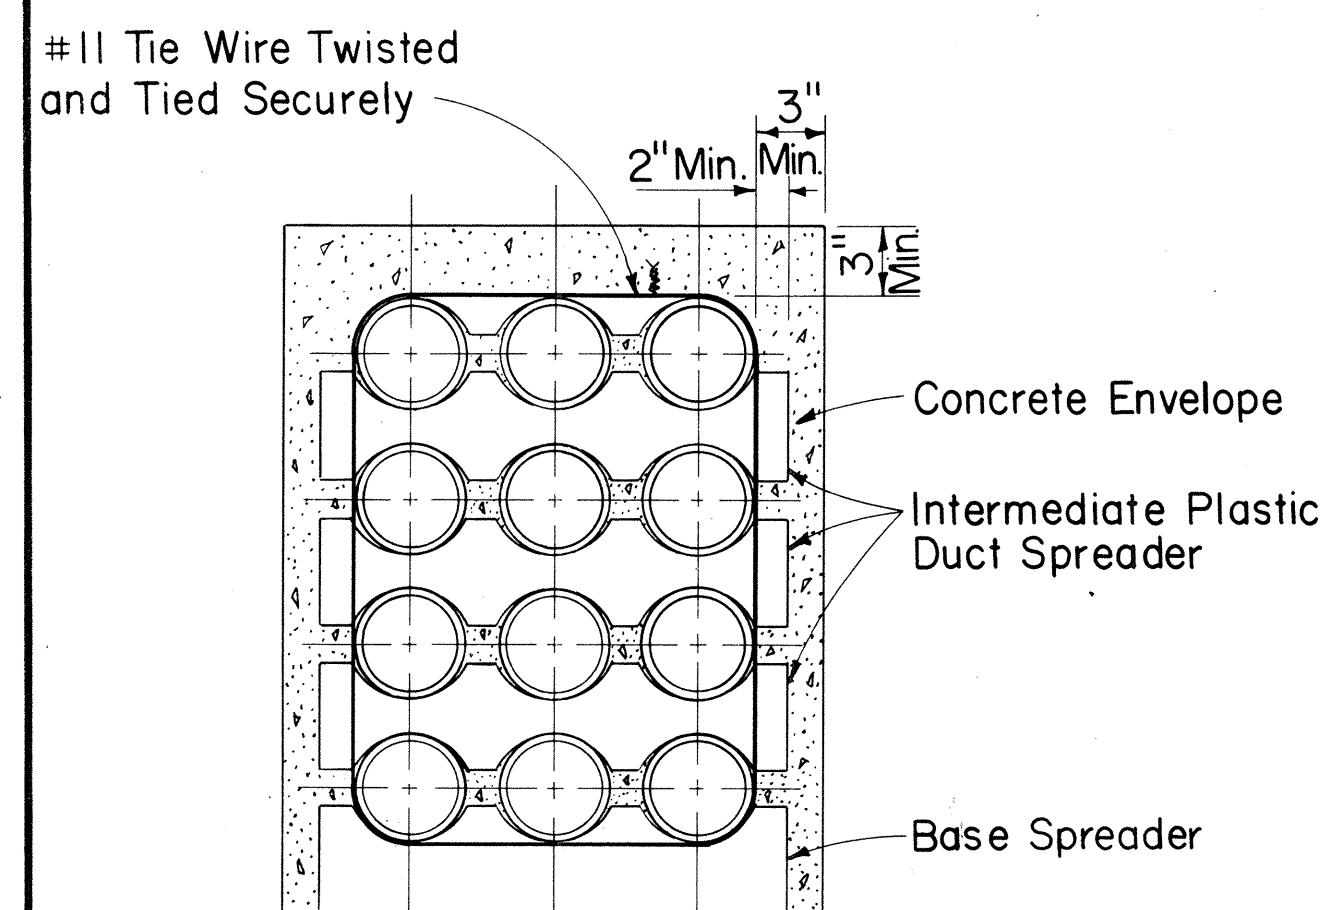

SECTION SHOWING SPACERS

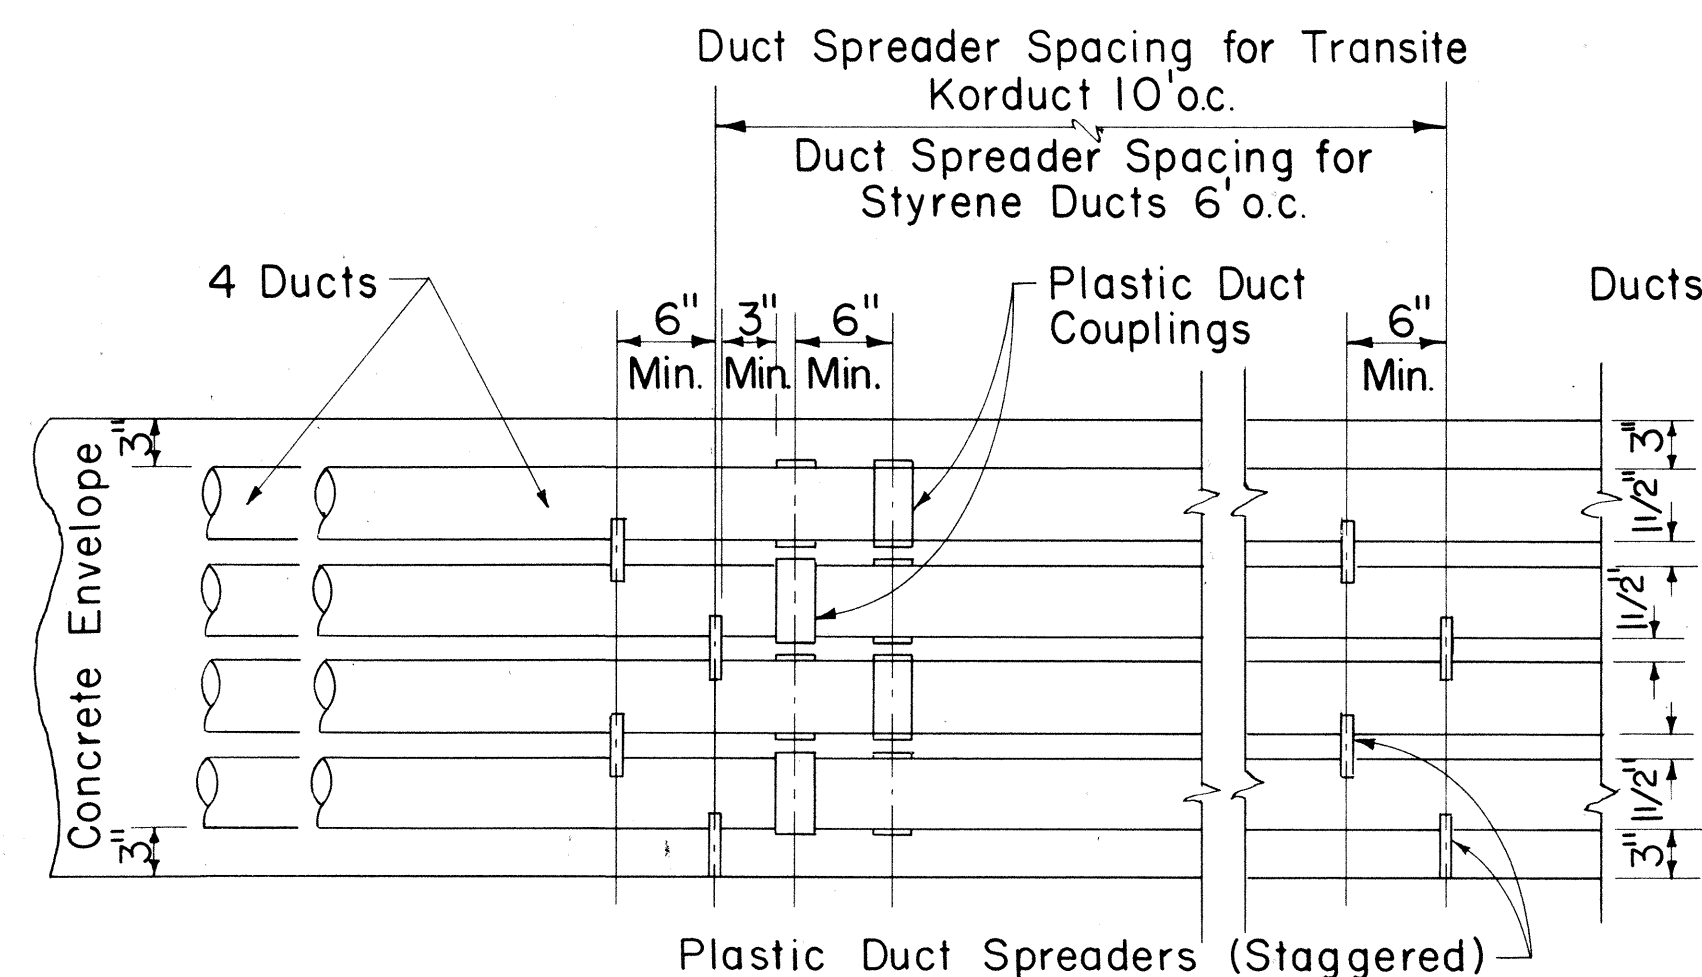

TYPICAL DUCT ENVELOPE ELEVATION
ARRANGEMENT OF COUPLING & PLASTIC SPACERS
Scale: 1" = 1'-0"

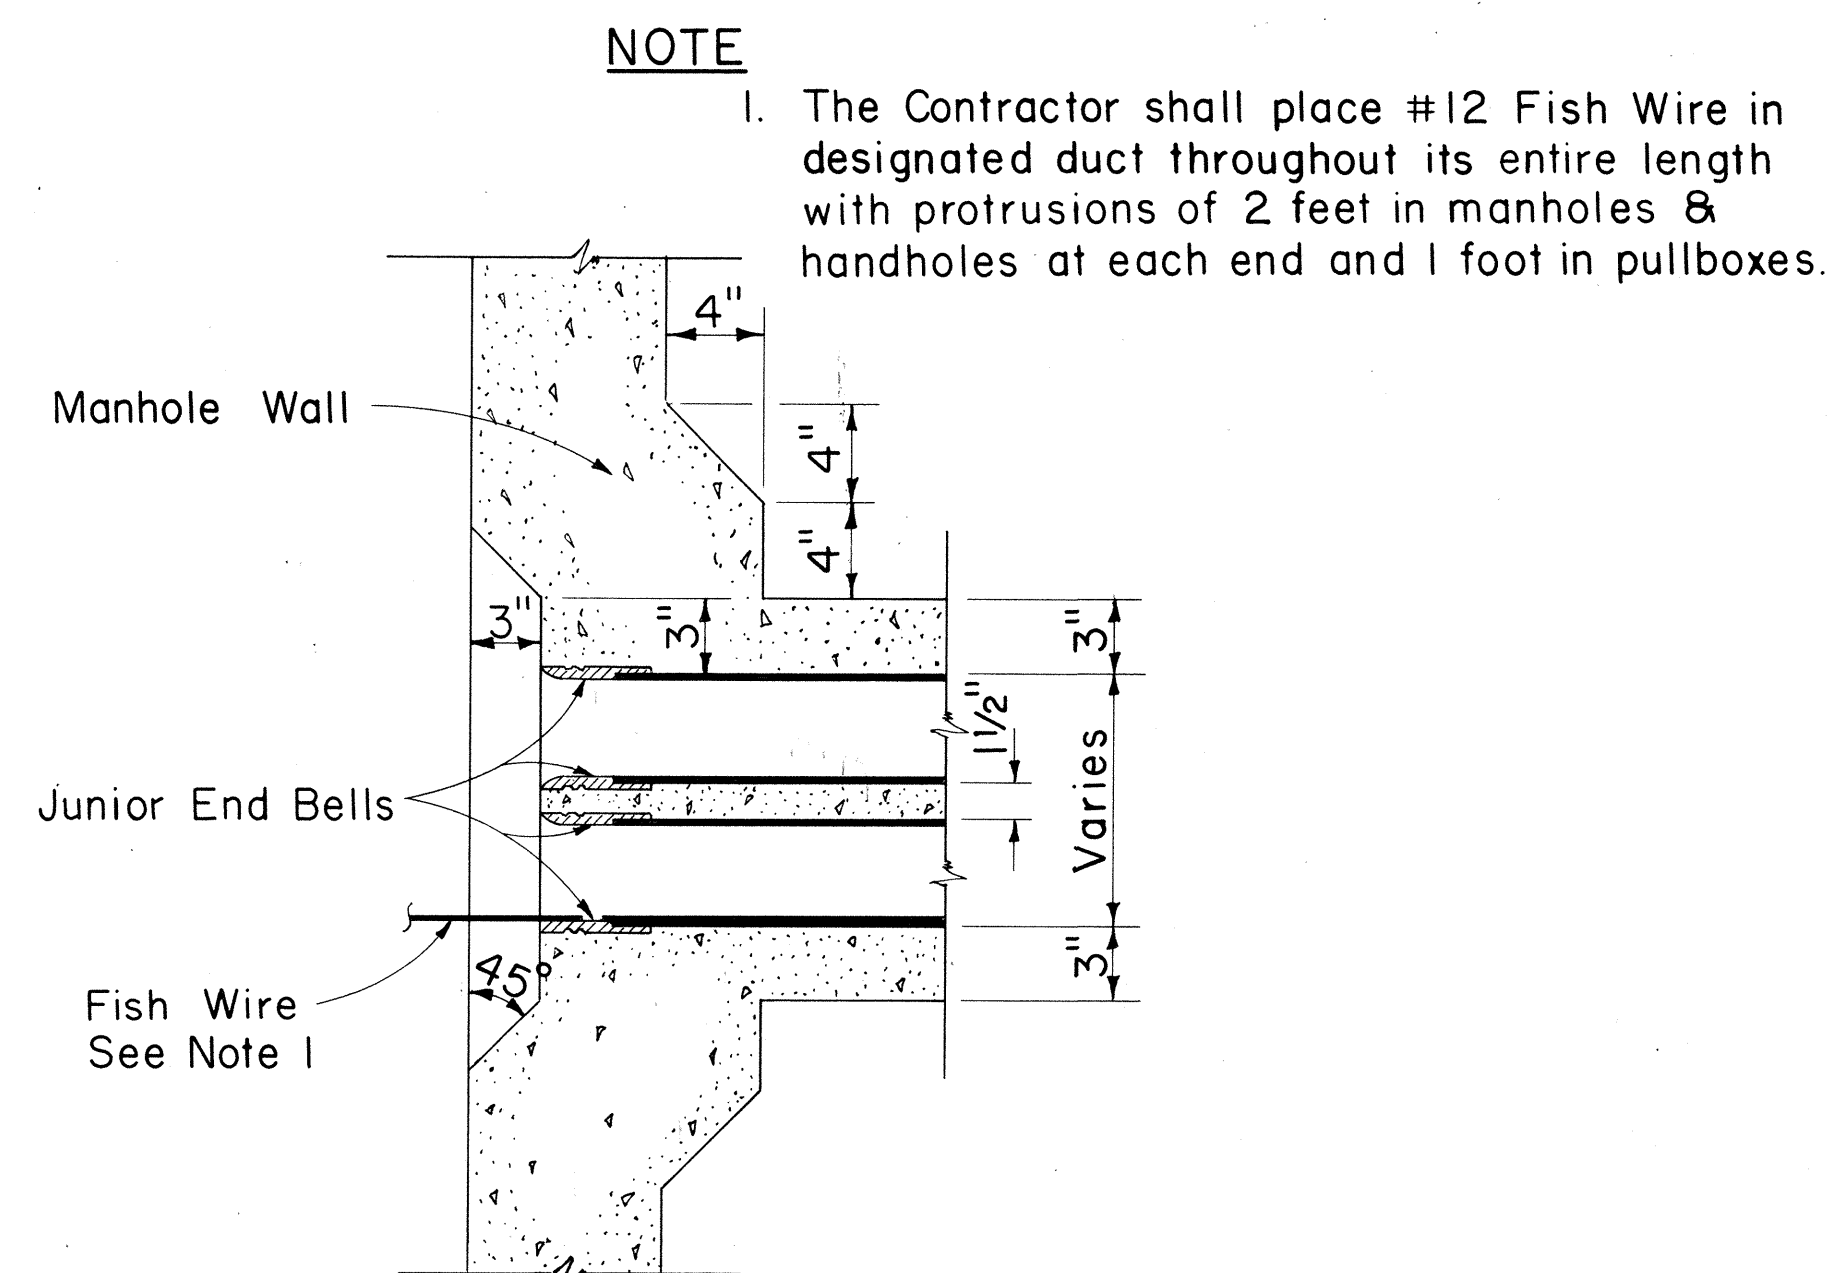

SECTION "F-F"
TYPICAL WINDOW DETAIL & JUNIOR END BELL
Scale: 1 1/2" = 1'-0"

NOTE

- The Contractor shall place #12 Fish Wire in designated duct throughout its entire length with protrusions of 2 feet in manholes & handholes at each end and 1 foot in pullboxes.

Supplement Sheet to Type "A-1" (Drawing Nos. 34060 & 34061), Type "A-2" (Drwg. Nos. 34062 & 34063) and Type "A-3" (Drwg. Nos. 34064 & 34065) Telephone M.H.

APPROVED:

[Signature] 8-20-68
Hawaiian Telephone Co., Ltd. Date








STATE OF HAWAII
DEPARTMENT OF TRANSPORTATION
HIGHWAYS DIVISION

STANDARD DETAILS
TYPE "A" MANHOLE
AND MISCELLANEOUS
TELEPHONE DETAILS

Scale: As Noted Date: 8/16/68

SHEET No. 23 OF 27 SHEETS

FED. ROAD DIST. NO.	STATE	FED. AID PROJ. NO.	FISCAL YEAR	SHEET NO.	TOTAL SHEETS
HAWAII	HAW.	IHI-1(64)12 UNIT 2 IHI-1(16)11	1969	72	128

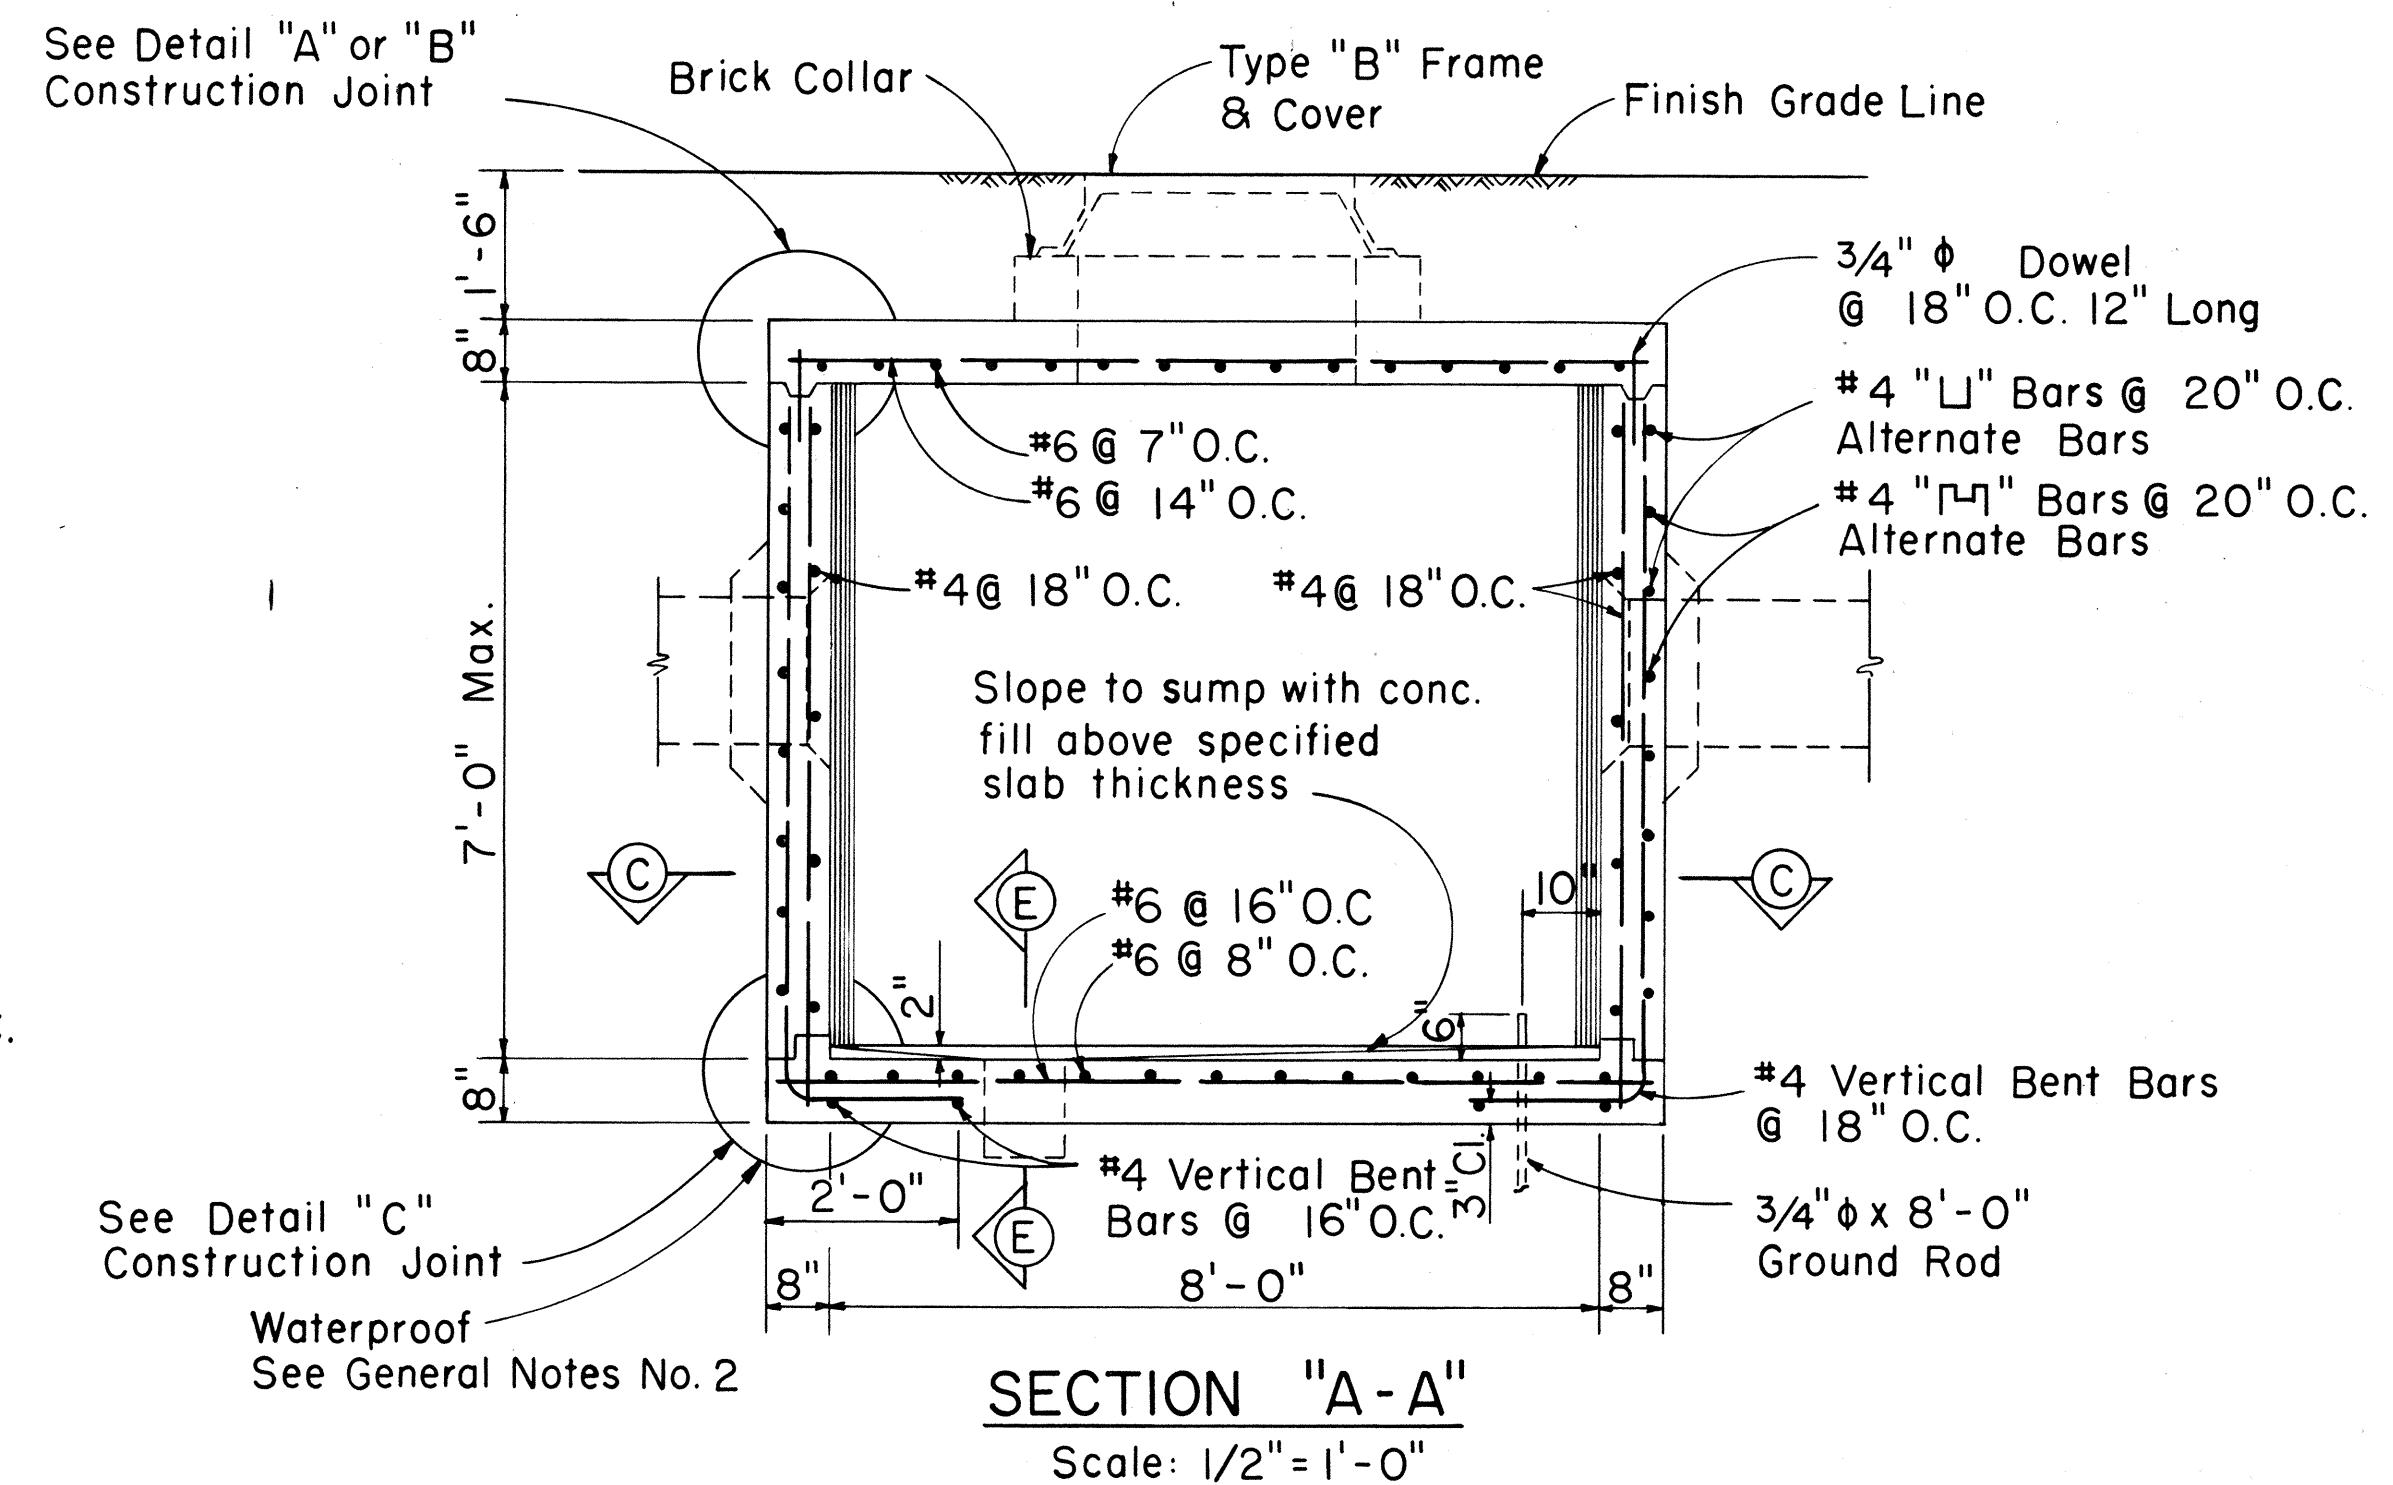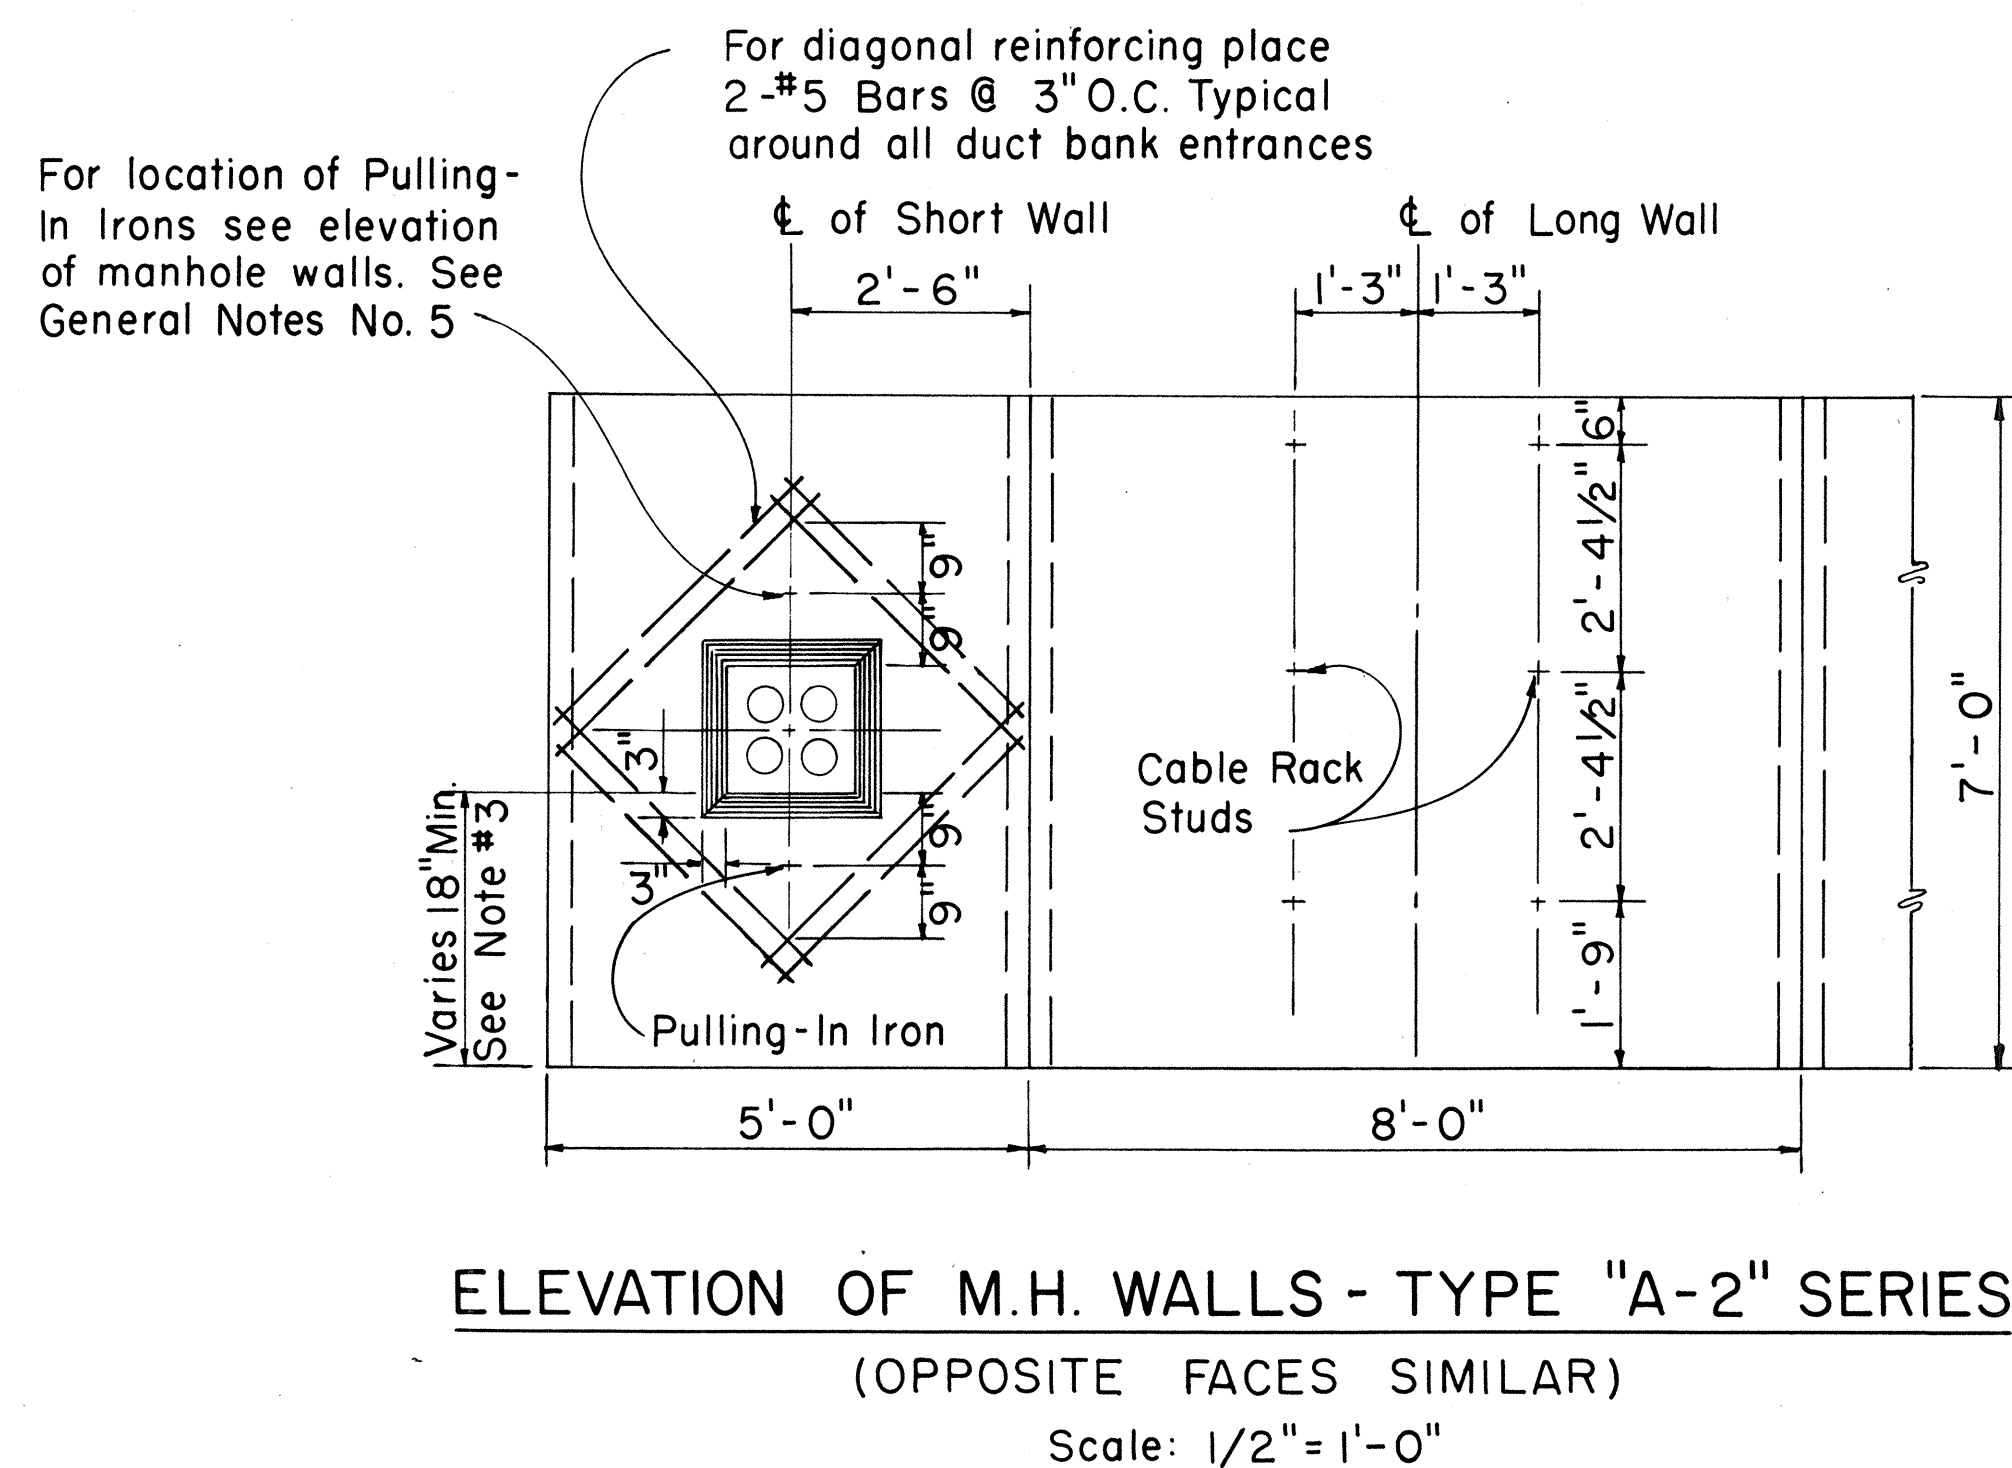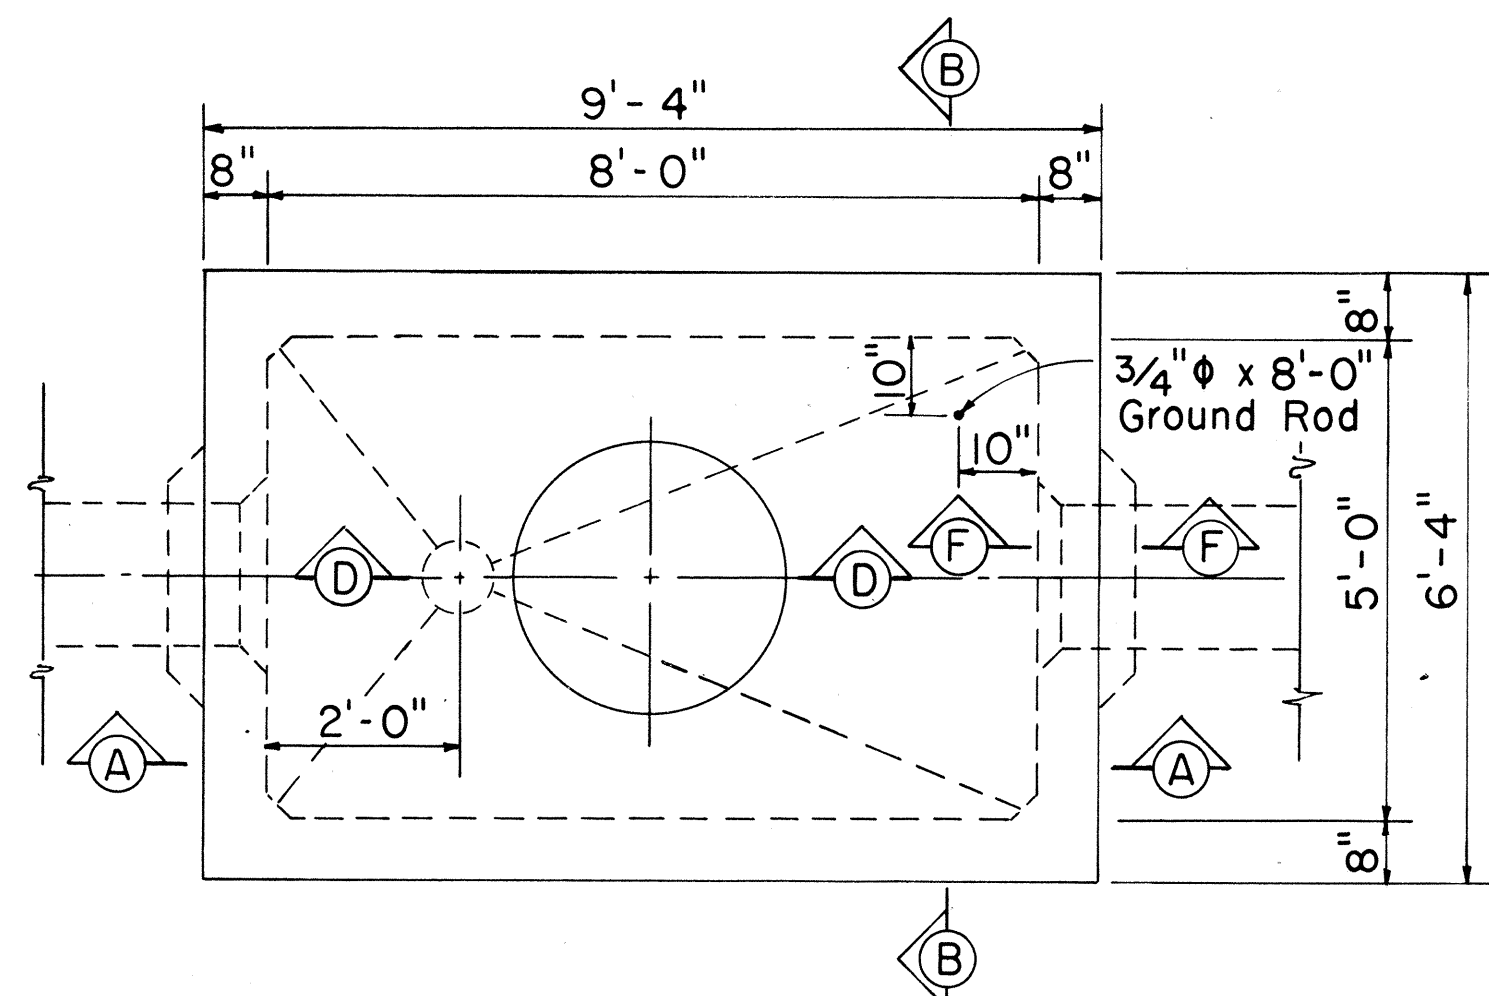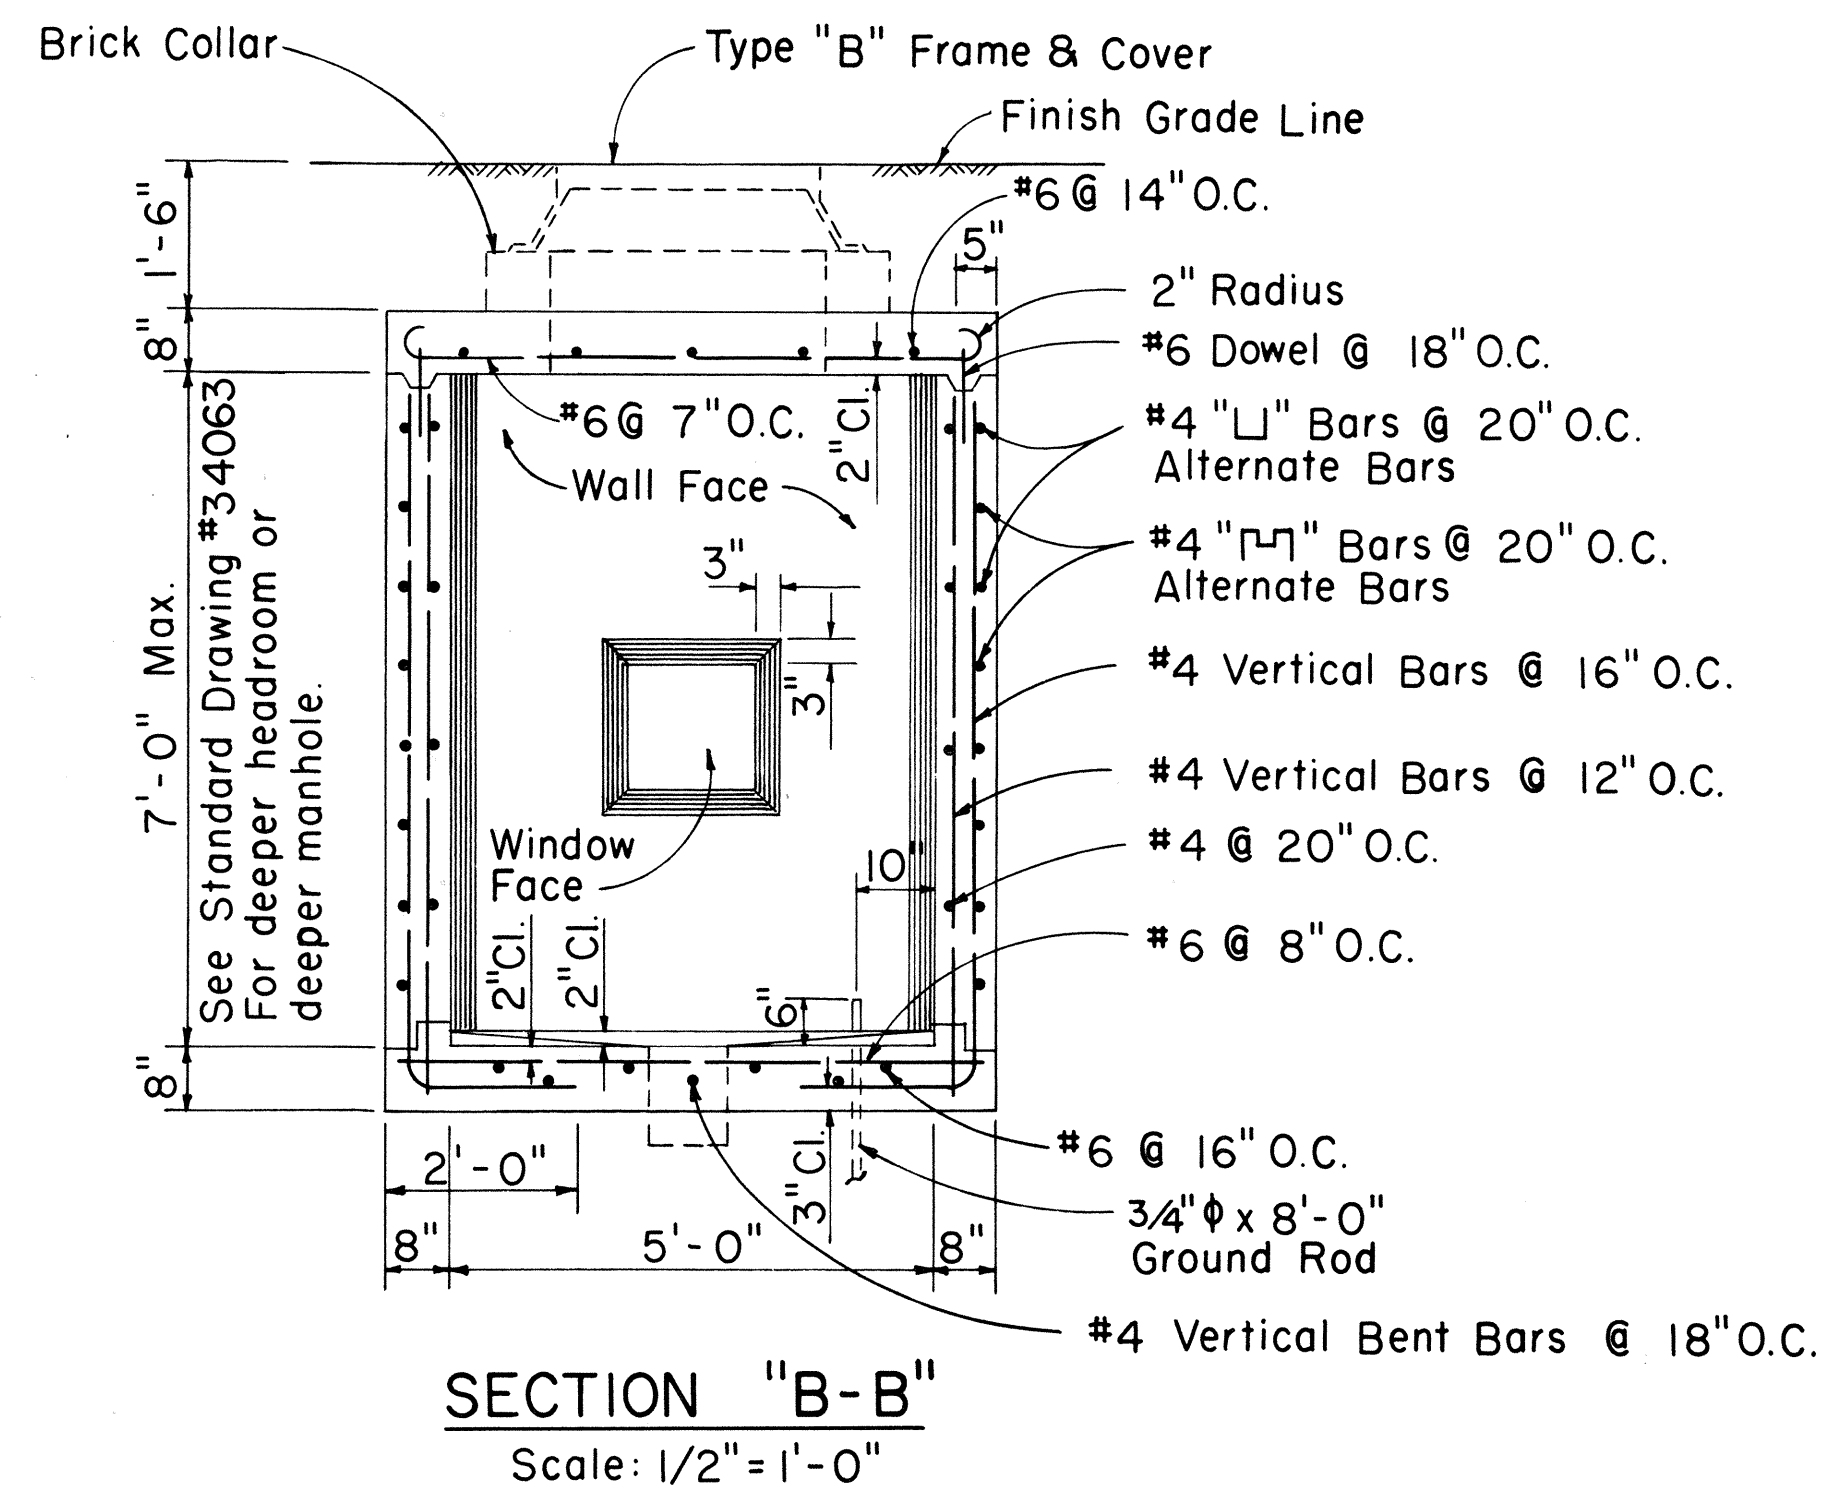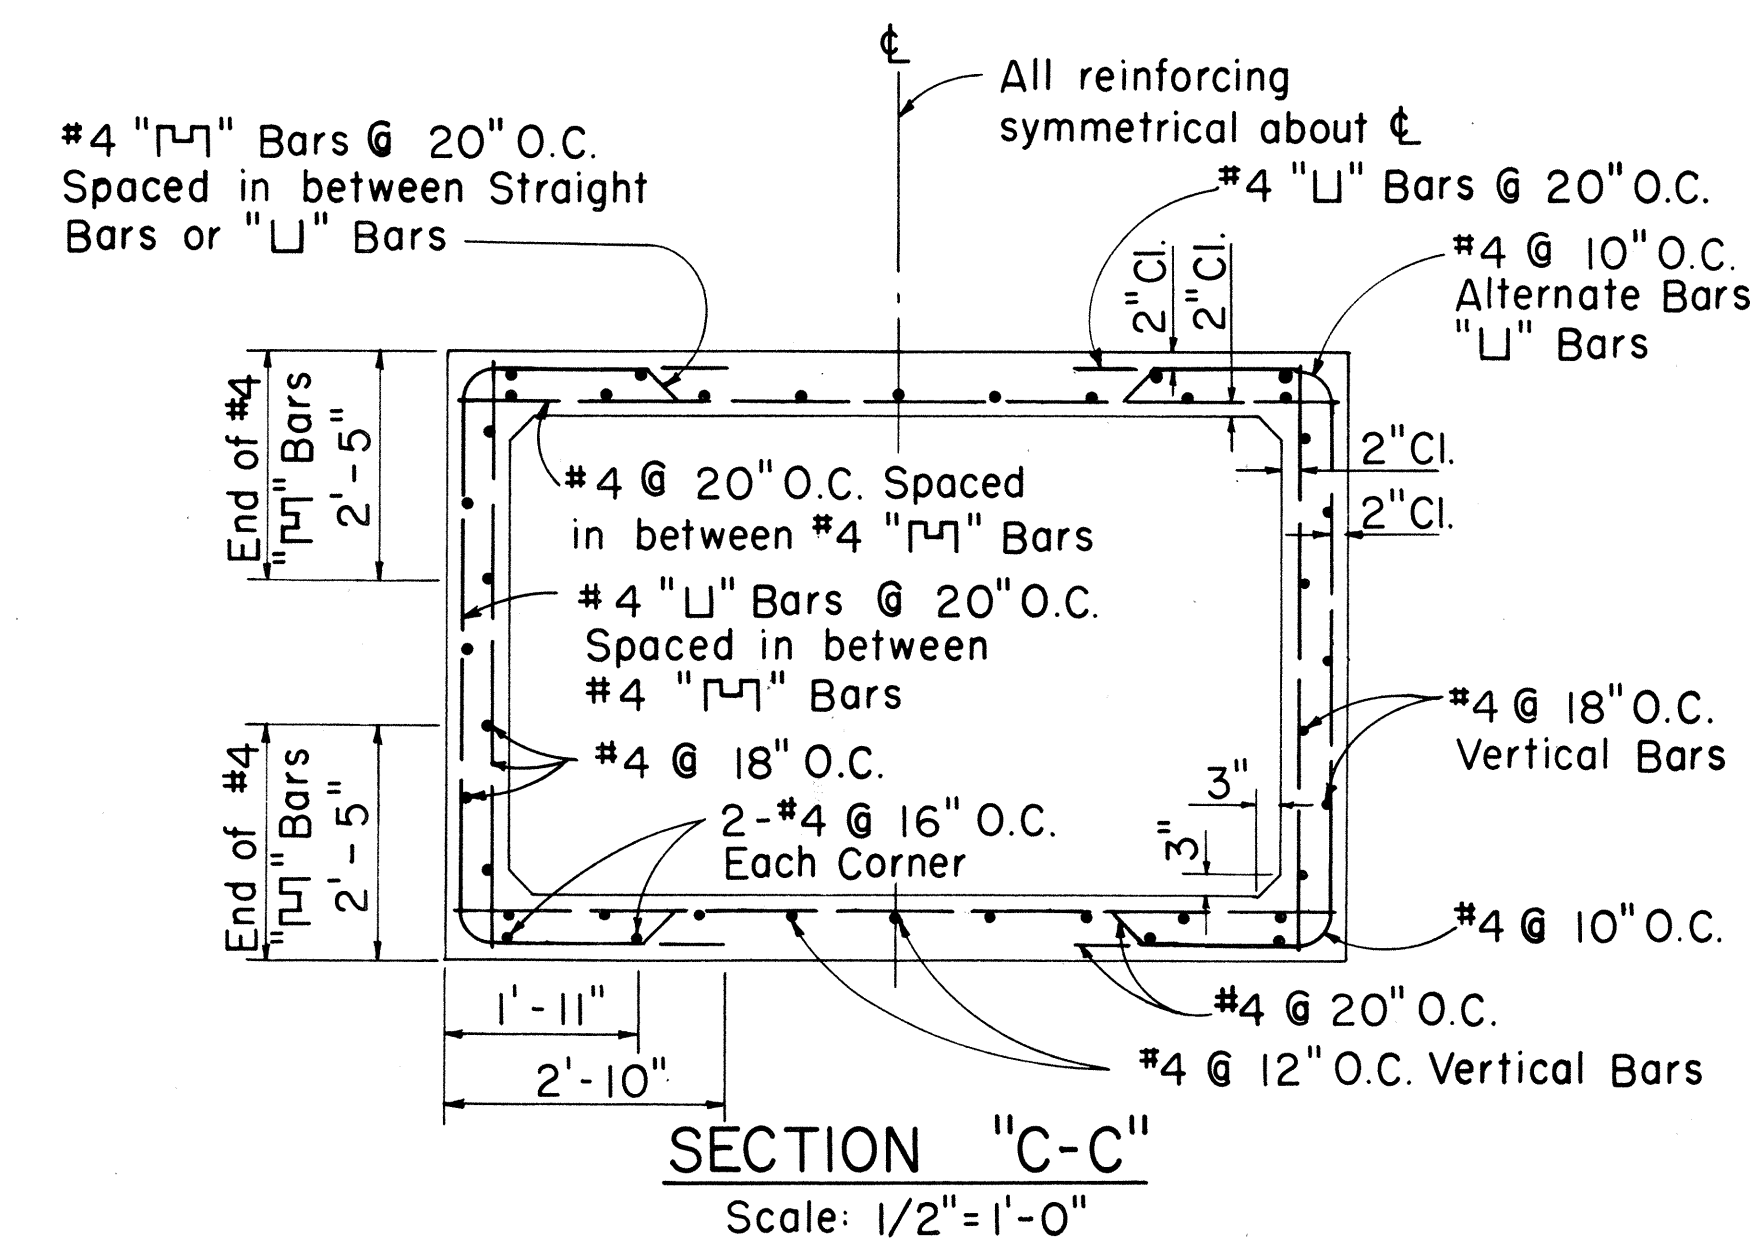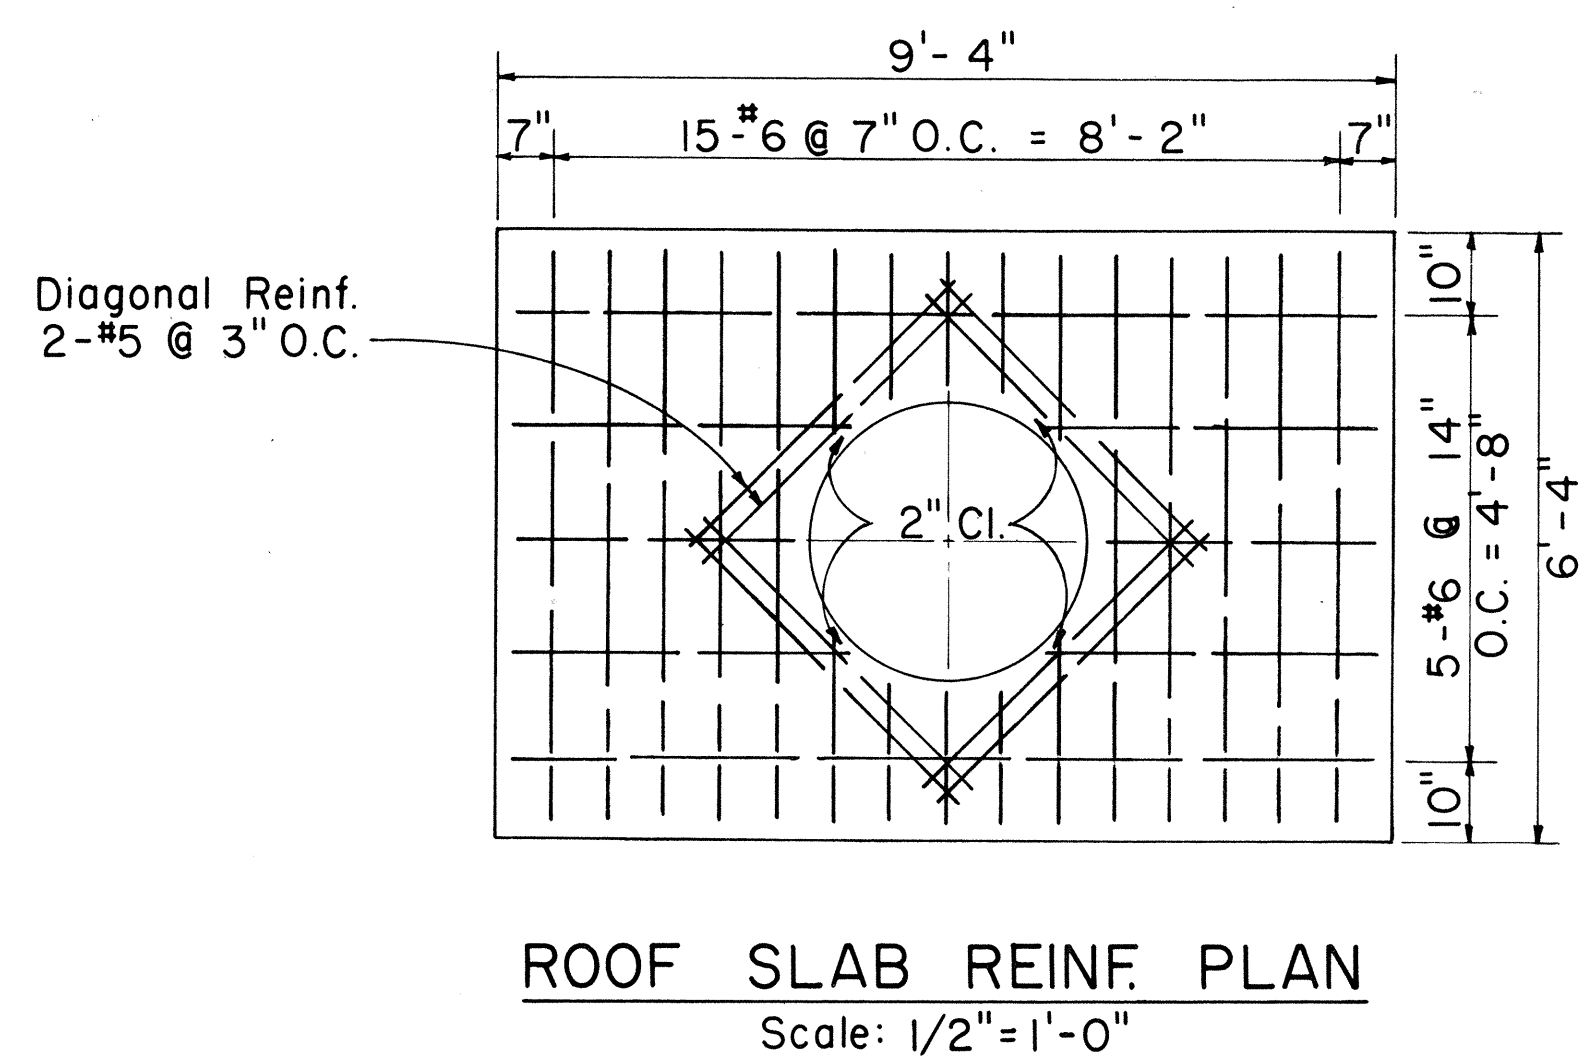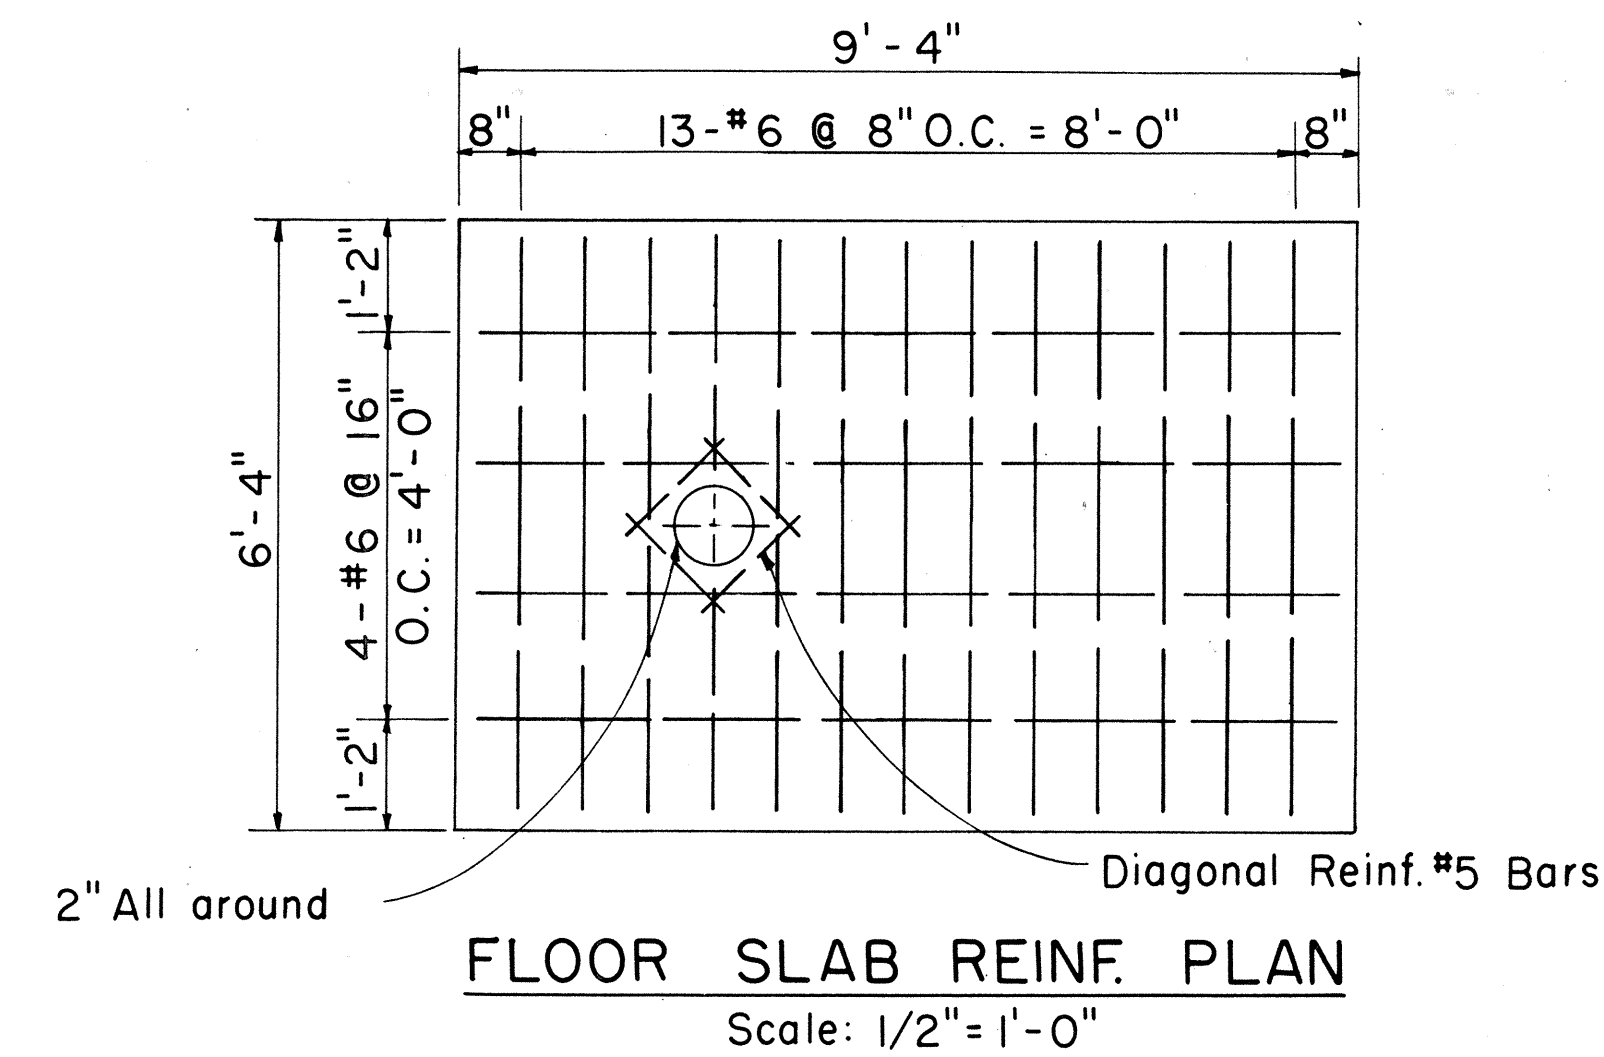

GENERAL NOTES:





- Design Data:
fs = 20,000 psi; fc = 3,000 psi; n = 10
w = Equivalent Fluid Pressure: 30#/ft²
- All Construction Joints shall be waterproofed with two applications of Thoro Seal or equal.
- For Duct Window location see Plan Profile Sheets for Elevations.
- Duct Window to suit - See Plan & Profile & Standard Detail Sheets for Location & Details.
- For Details "A", "B", "C", Sections "D-D", "E-E", "F-F" and other miscellaneous Manhole Construction Details see Supplement Sheet to Type "A-1", "A-2" and "A-3" Telephone Manholes.

Manhole Classification
Width & Length Designation "2" = 5.0' x 8.0'
Manhole Headroom

APPROVED:
[Signature]
Hawaiian Telephone Co., Ltd. 8-70-68
Date


H.T. Co., Ltd. Drawing No. 34062
STATE OF HAWAII
DEPARTMENT OF TRANSPORTATION
HIGHWAYS DIVISION
**TYPE "A-2" MANHOLES
FOR 6.0' TO 7.0'
HEADROOM**
Scale: As Noted Date: 8/16/68
SHEET No. 24 OF 27 SHEETS

FED. ROAD DIST. NO.	STATE	FED. AID PROJ. NO.	FISCAL YEAR	SHEET NO.	TOTAL SHEETS
HAWAII	HAW.	I-HI-1(64)-12 UNIT 2 I-HI-1(16)-11	1962	73	128

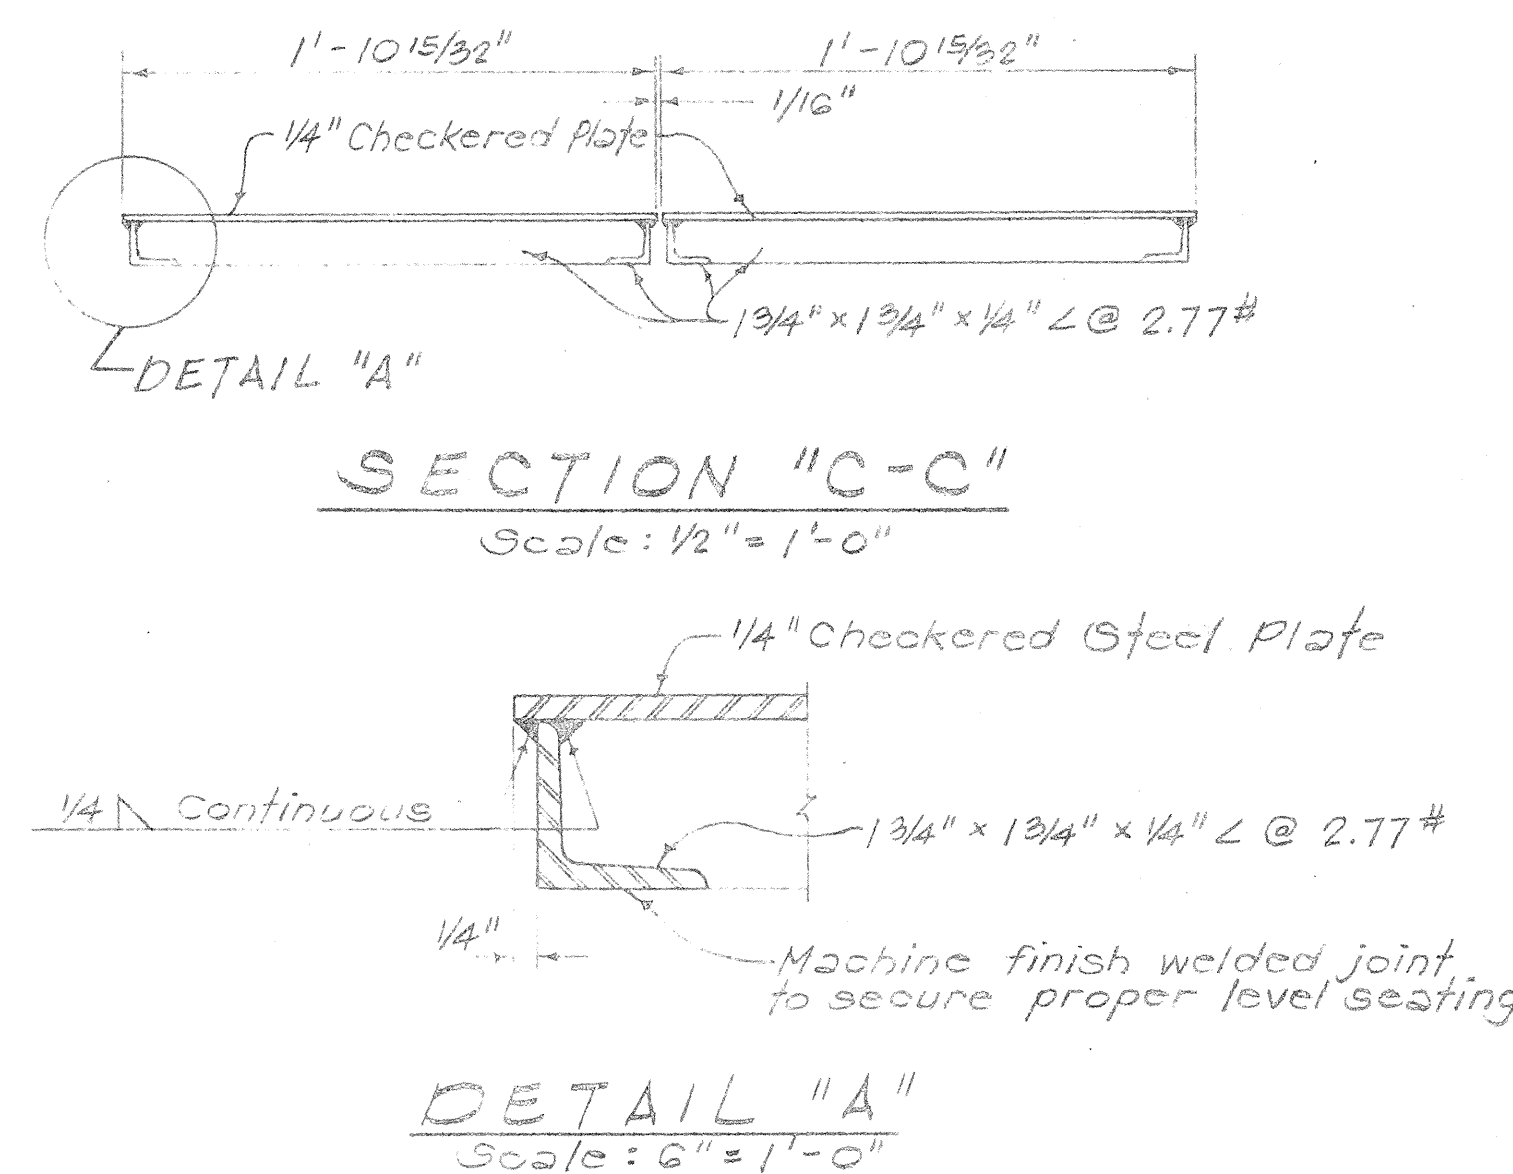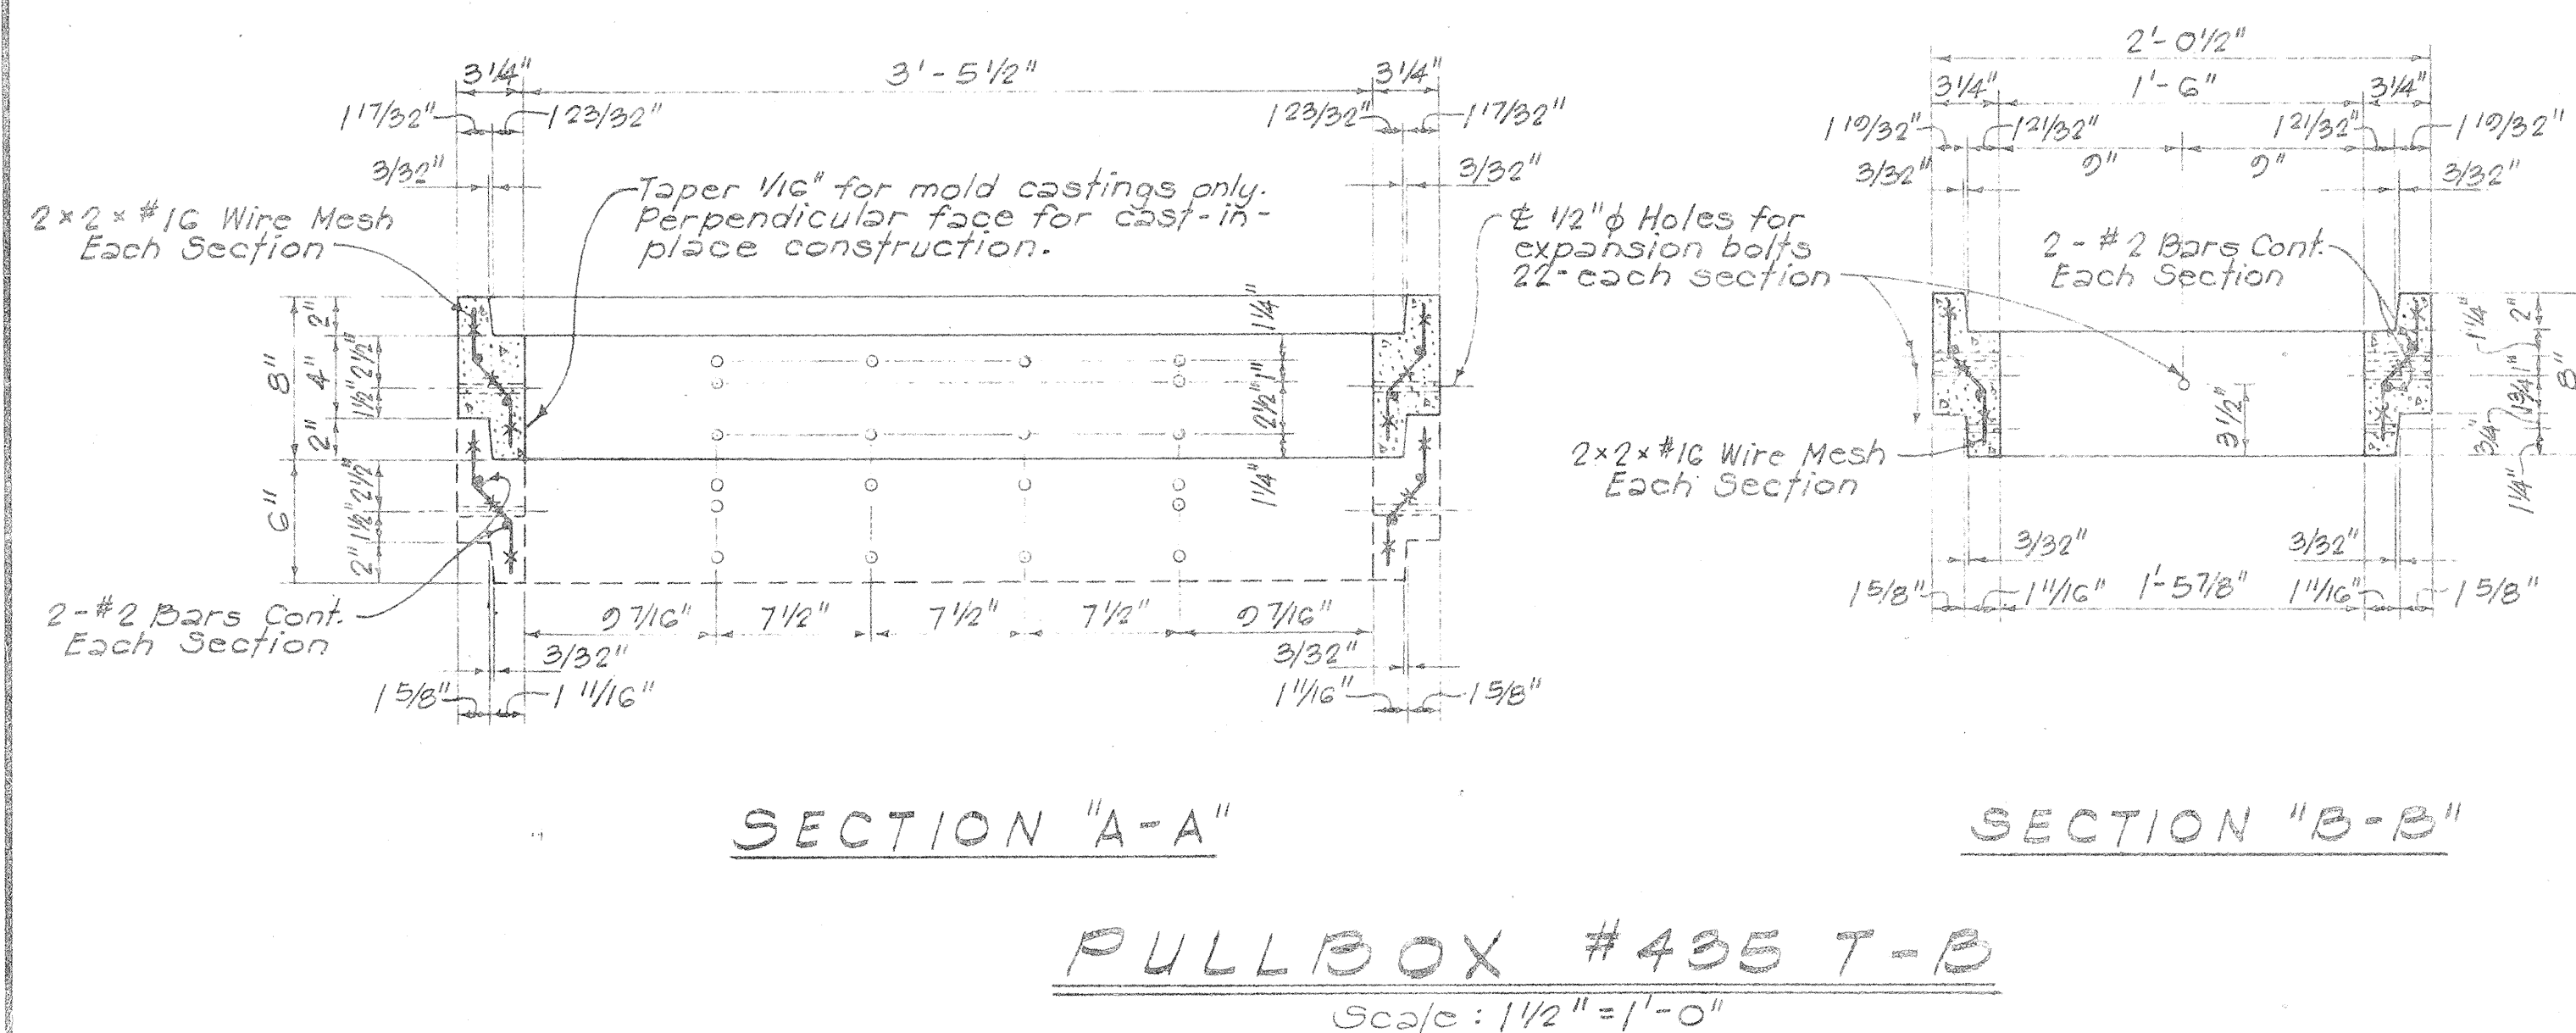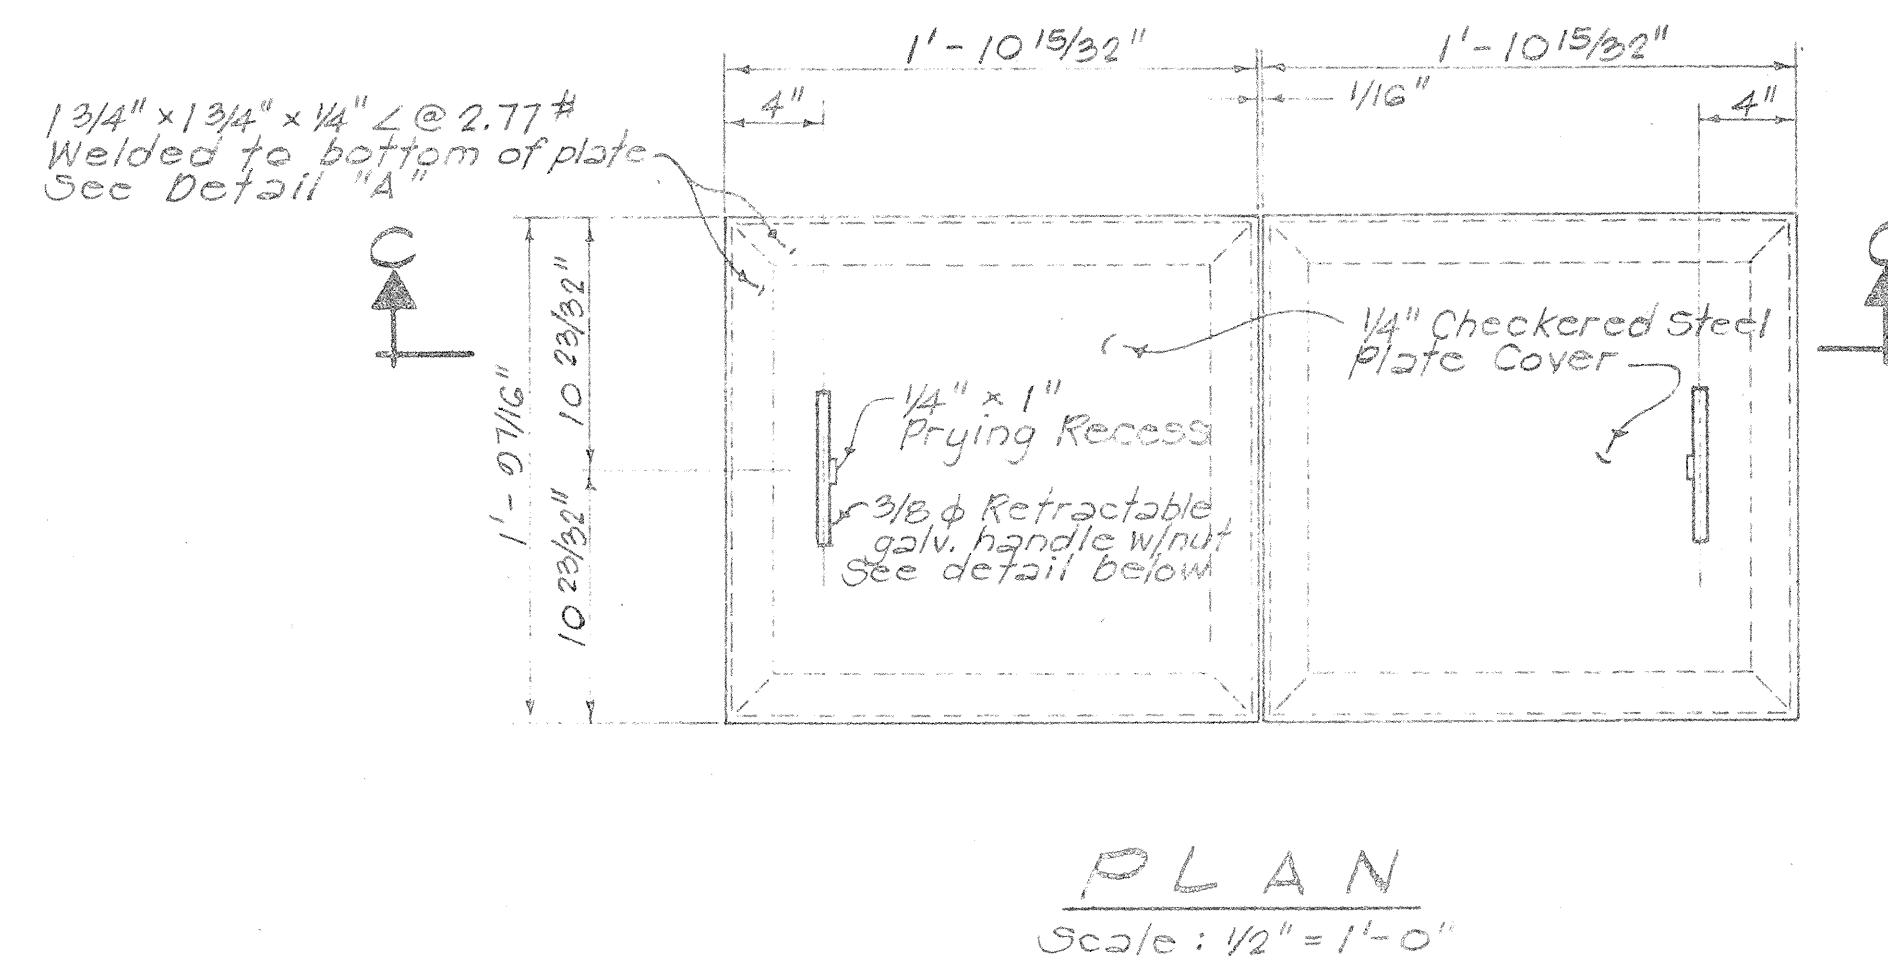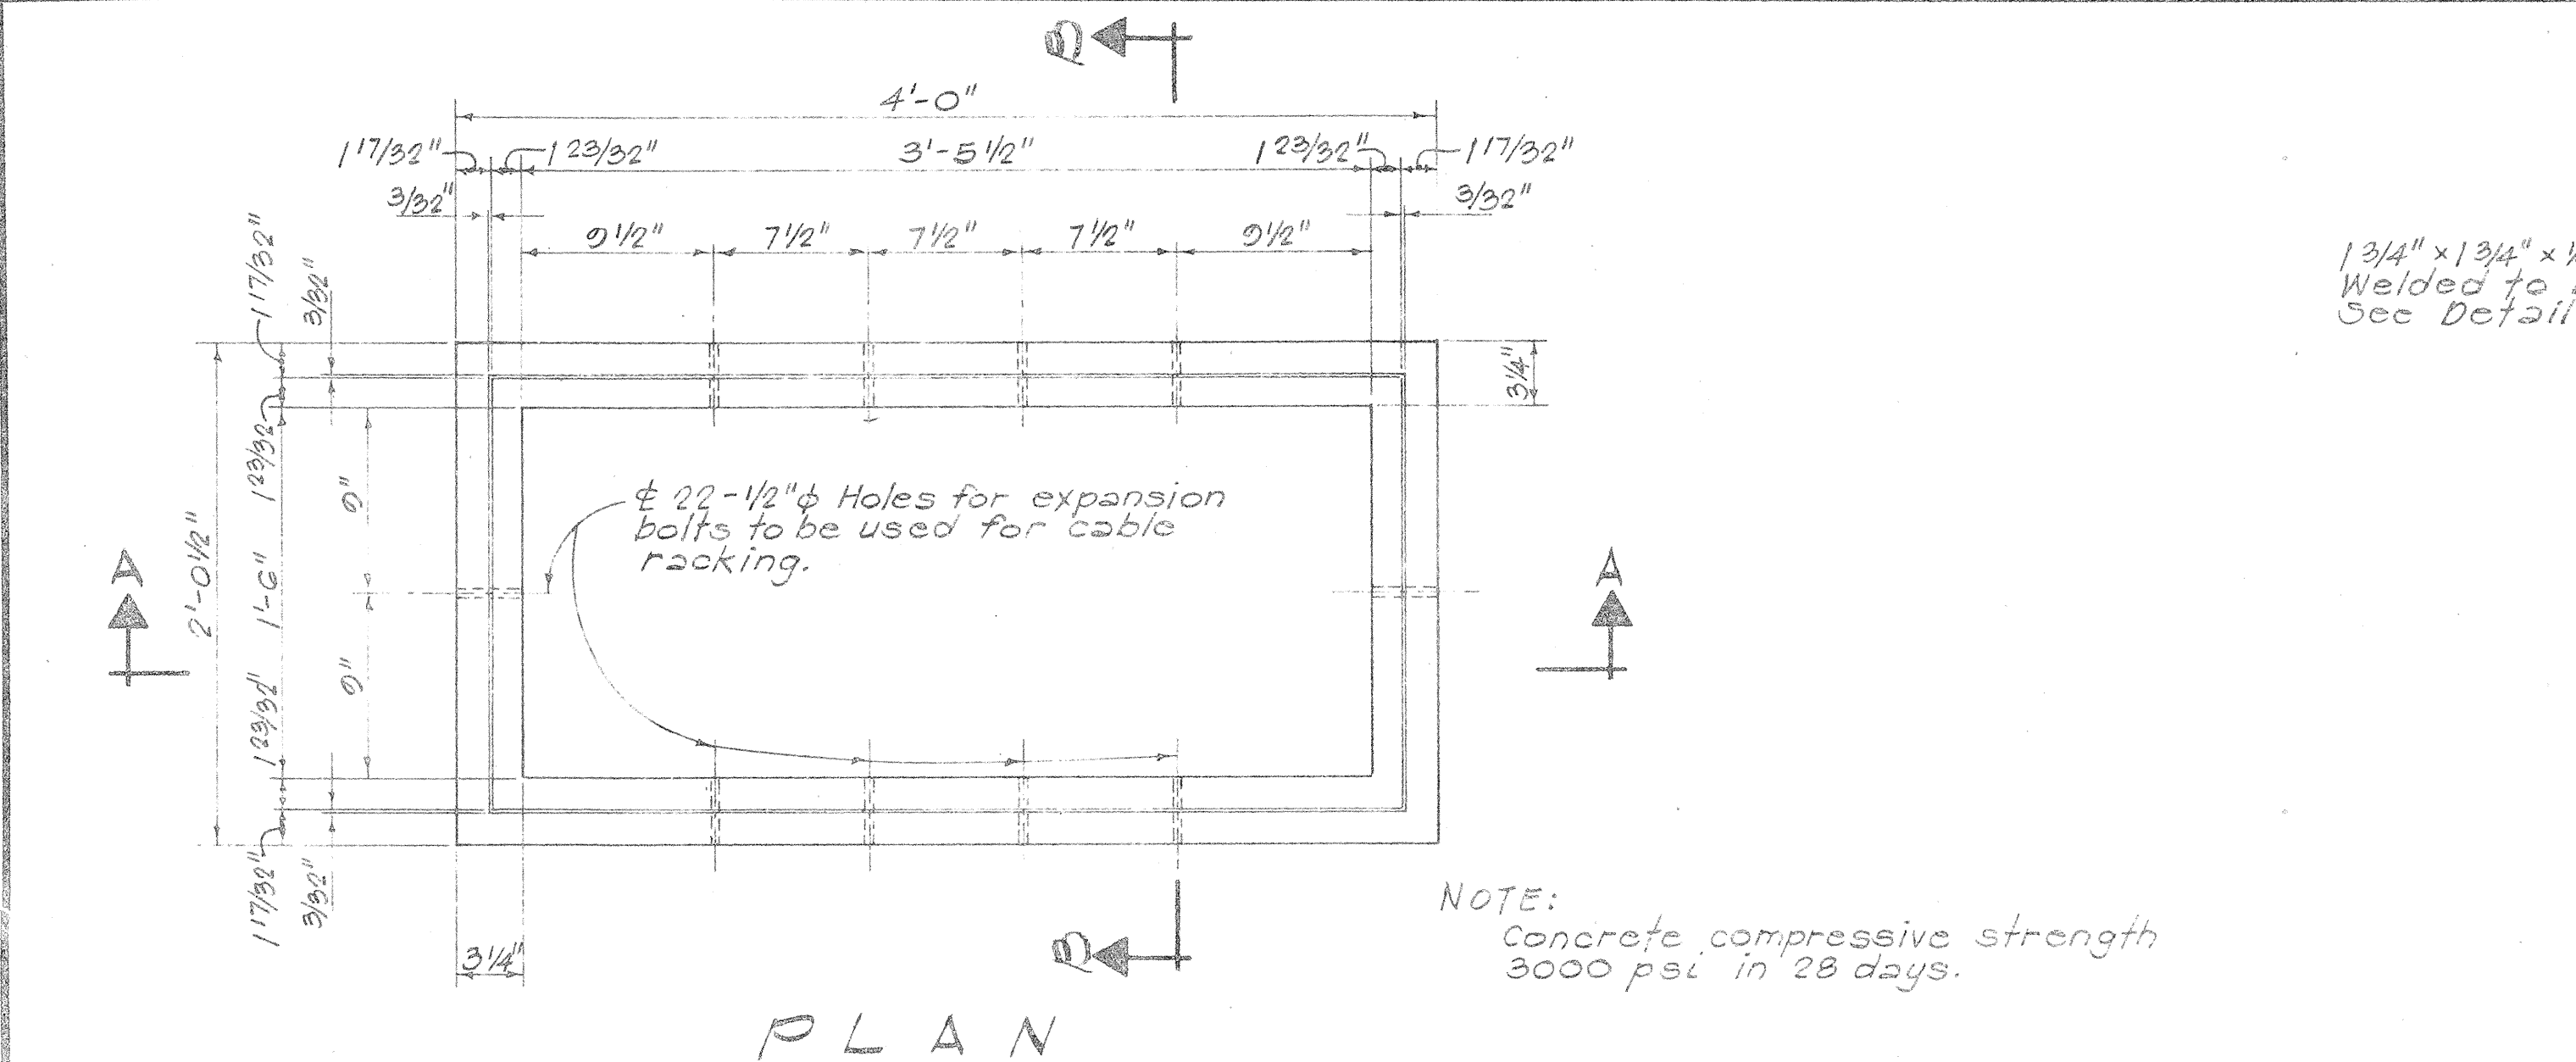

NOTE:
After fabrication of cover, apply 1 coat of silver paint to both sides.

CHECKERED STEEL PLATE COVERS (FOR LIGHT LOADING AREAS)

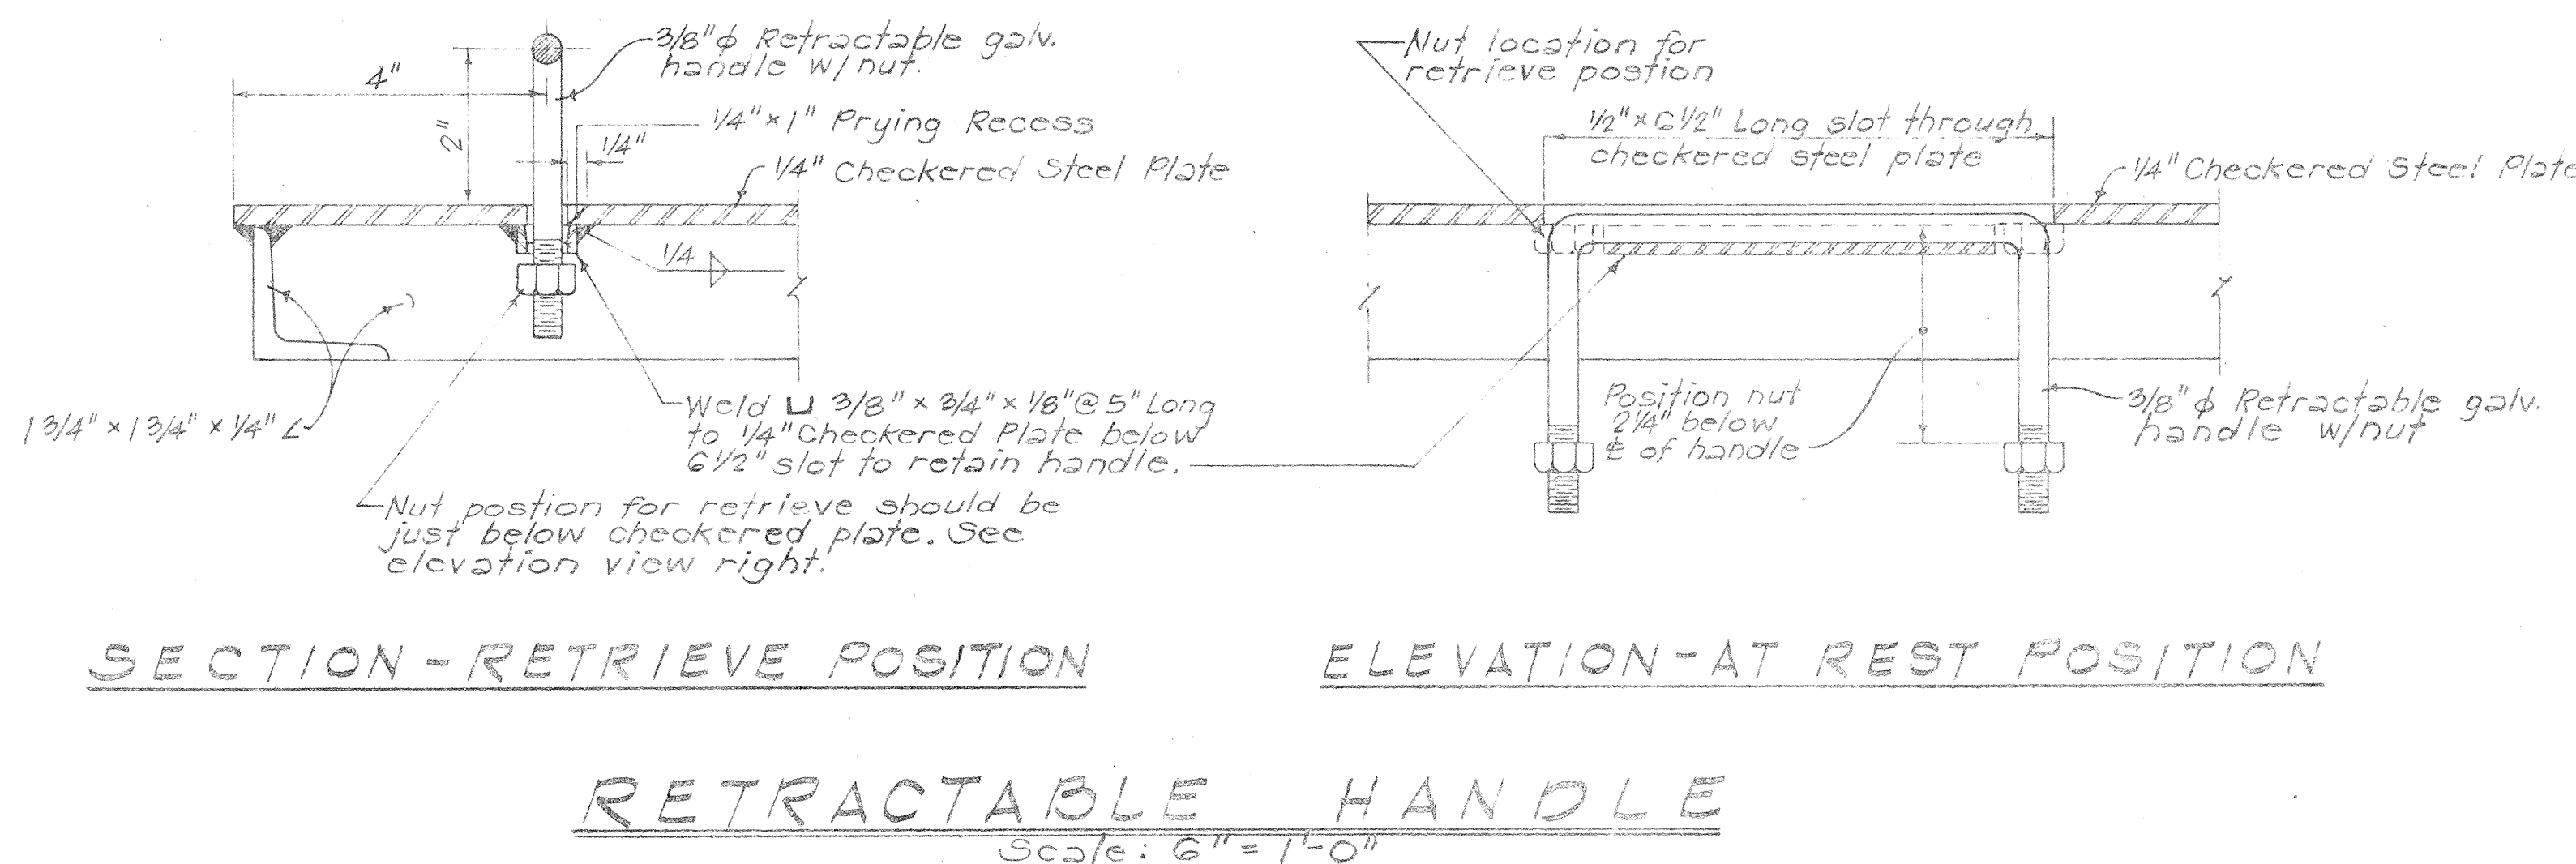

APPROVED: *[Signature]* Date: 6-20-62
Hawaiian Telephone Company

STATE OF HAWAII DEPARTMENT OF TRANSPORTATION HIGHWAYS DIVISION	
LARGE PULLBOX NO. 435 T-B	
TELEPHONE	
INTERSTATE ROUTE H-1 PROJ. NO. I-HI-1(16)-11	
Scale: 1" = 50'	Date: 6/16/62
SHEET NO. 25 OF 27 SHEETS	

FED. ROAD DIST. NO.	STATE	FED. AID PROJ. NO.	FISCAL YEAR	SHEET NO.	TOTAL SHEETS
HAWAII	HAW.	I-HI-1(64):12 UNIT 2	1969	74	128
		I-HI-1(16):11			










GENERAL NOTES

- The general conditions of Specification Sht. 16103 shall govern throughout the entire work.
- Concrete shall be Class A-1 conforming to the requirements of Section 47 of the special provisions.
- CONCRETE FINISH:
Top of Handhole - Wood floated (side walk finish) according to Division of Highways, State of Hawaii or Division of Engineering, City & County of Honolulu specifications which ever the case may be, unless otherwise directed.
* Floor - Smooth metal trowelled.
* Exposed Wall Surfaces & Edges - Smooth and free from defects.
* CONCRETE POURING:
Notify The Hawaiian Electric Co., Inc. Engineering Department 72 hours before pouring any concrete.
All concrete shall be poured in the presence of H.E.Co. Engineer or its representative.
- REINFORCING:
Round deformed bars, new billet stock intermediate grade A.S.T.M. A15. All hooked bars shall have A.C.I. standard hook unless otherwise shown.
- FORMS:
Form handhole to size & shape as shown. Exterior face of handhole walls shall be formed except:
A) Excavation in solid material such as coral or rock - neat cut - no forms required.
B) Excavation in solid materials other than coral & rock - lining such as salvaged corrugated iron, cane, etc. shall be used.
- PULLING EYE:
For location & number required, see duct entrance plan of project concerned.
- DRAINAGE:
Slope floor down 1/2" to sump.
Slope top of handhole to match existing sidewalk grade. In installations outside of sidewalk areas project top of handhole 1" above grade.
- FINISH STEEL WORK:
Angle frames for removable concrete slabs, lifting device & pulling eye shall be hot dip galvanized after fabrication.
- EXCAVATION:
Excavate for handhole to accurate alignment grades & dimensions as shown on drawing. All excavation must be approved by the Engineering Department The Hawaiian Electric Co., Inc., before installing precast handhole. All excess cut shall be backfilled with concrete or crushed lava rock.
- BACKFILL:
Remove all debris before backfilling. Backfill in accordance with latest specifications of and subject to approval of Division of Highways, State of Hawaii or Division of Engineering, City & County of Honolulu whichever the case may be unless otherwise directed.
- For duct line construction standards, see H.E.Co. Dwg. U-18585, Revision #2 and specifications sheet U-18585A.
- DUCTS:
For size, location & number required see duct entrance plan of project concerned.
- ALL MATERIALS SHALL BE NEW AND SHALL BE MANUFACTURED IN THE UNITED STATES OF AMERICA.
- This handhole to be used in areas not subject to vehicular traffic.



* Applicable to Handhole #18844 only. (For details of Handhole #18844 (See Sht. 75))

APPROVED: *D. Henderson* 8-20-68
Hawaiian Electric Company, Inc. Date

STATE OF HAWAII DEPARTMENT OF TRANSPORTATION HIGHWAYS DIVISION	
DOUBLE PRECAST HANDHOLE (# C-2378)	
ELECTRICAL	
INTERSTATE ROUTE H-1 PROJ. NO. I-HI-1(16):11	
Scale: As Shown	Date: 8/10/68
SHEET No. 26 OF 27 SHEETS	

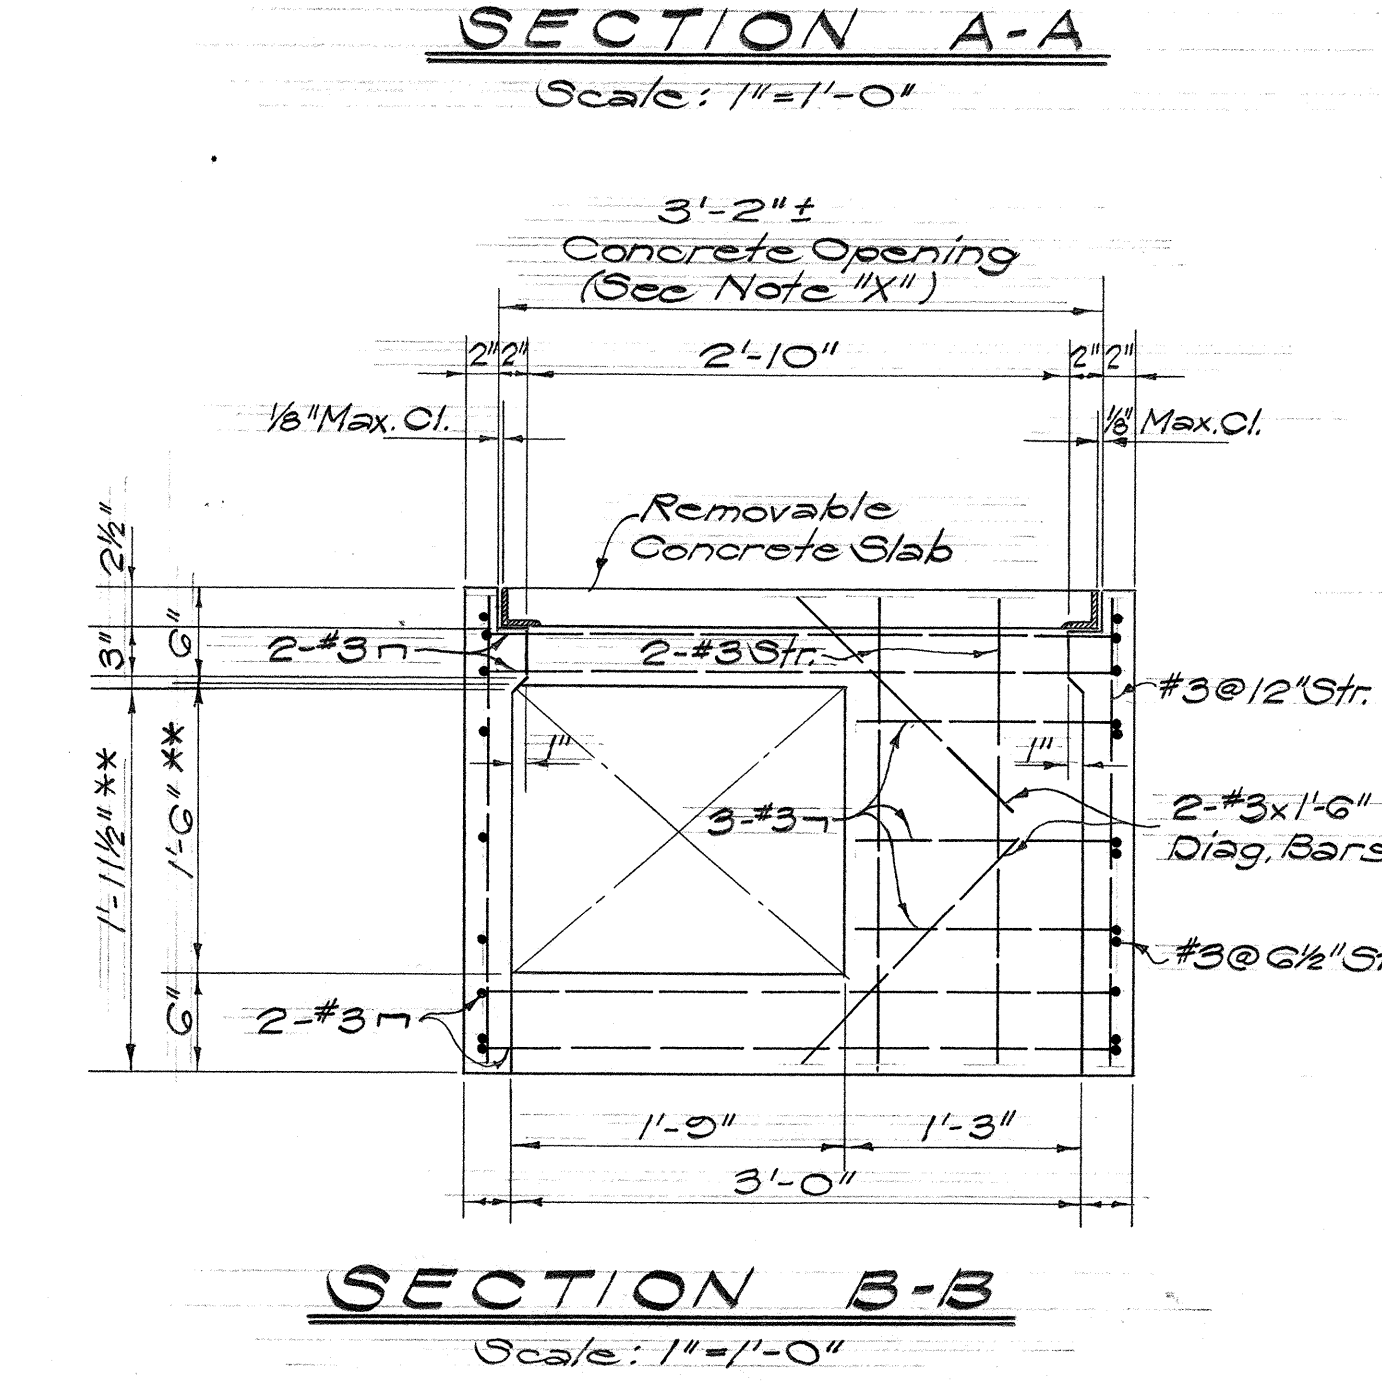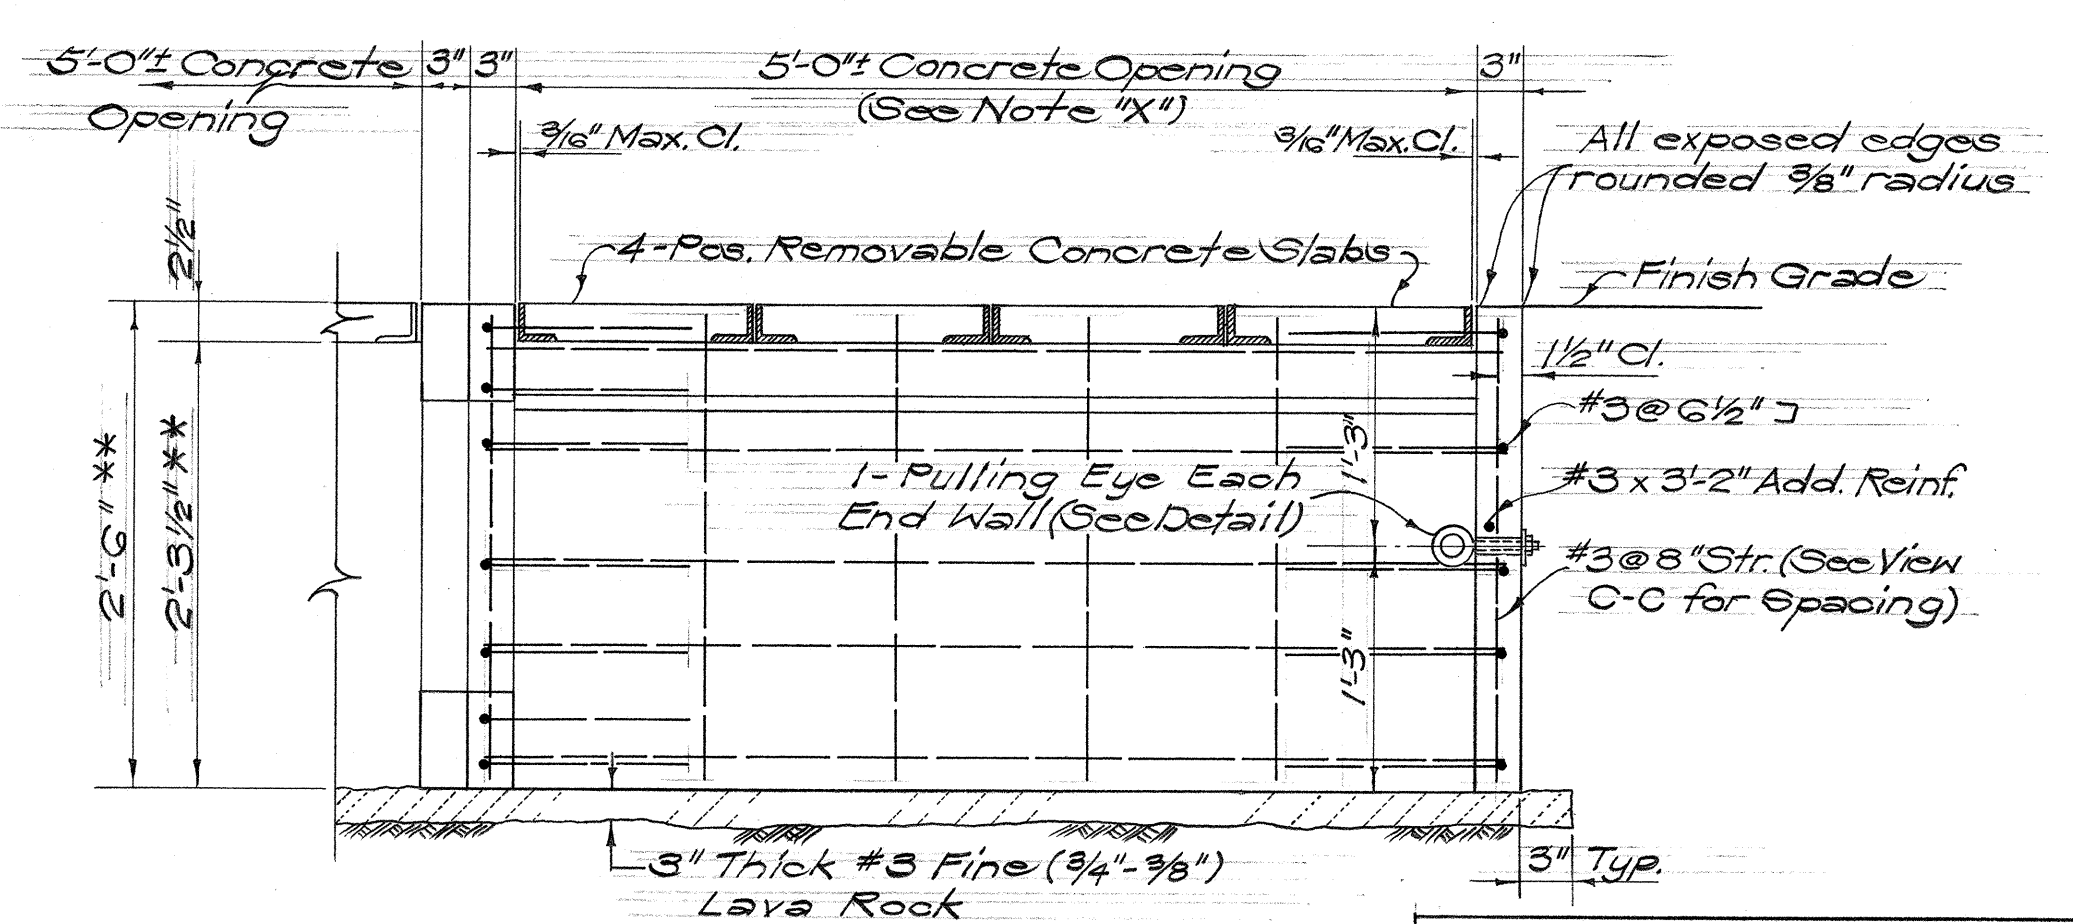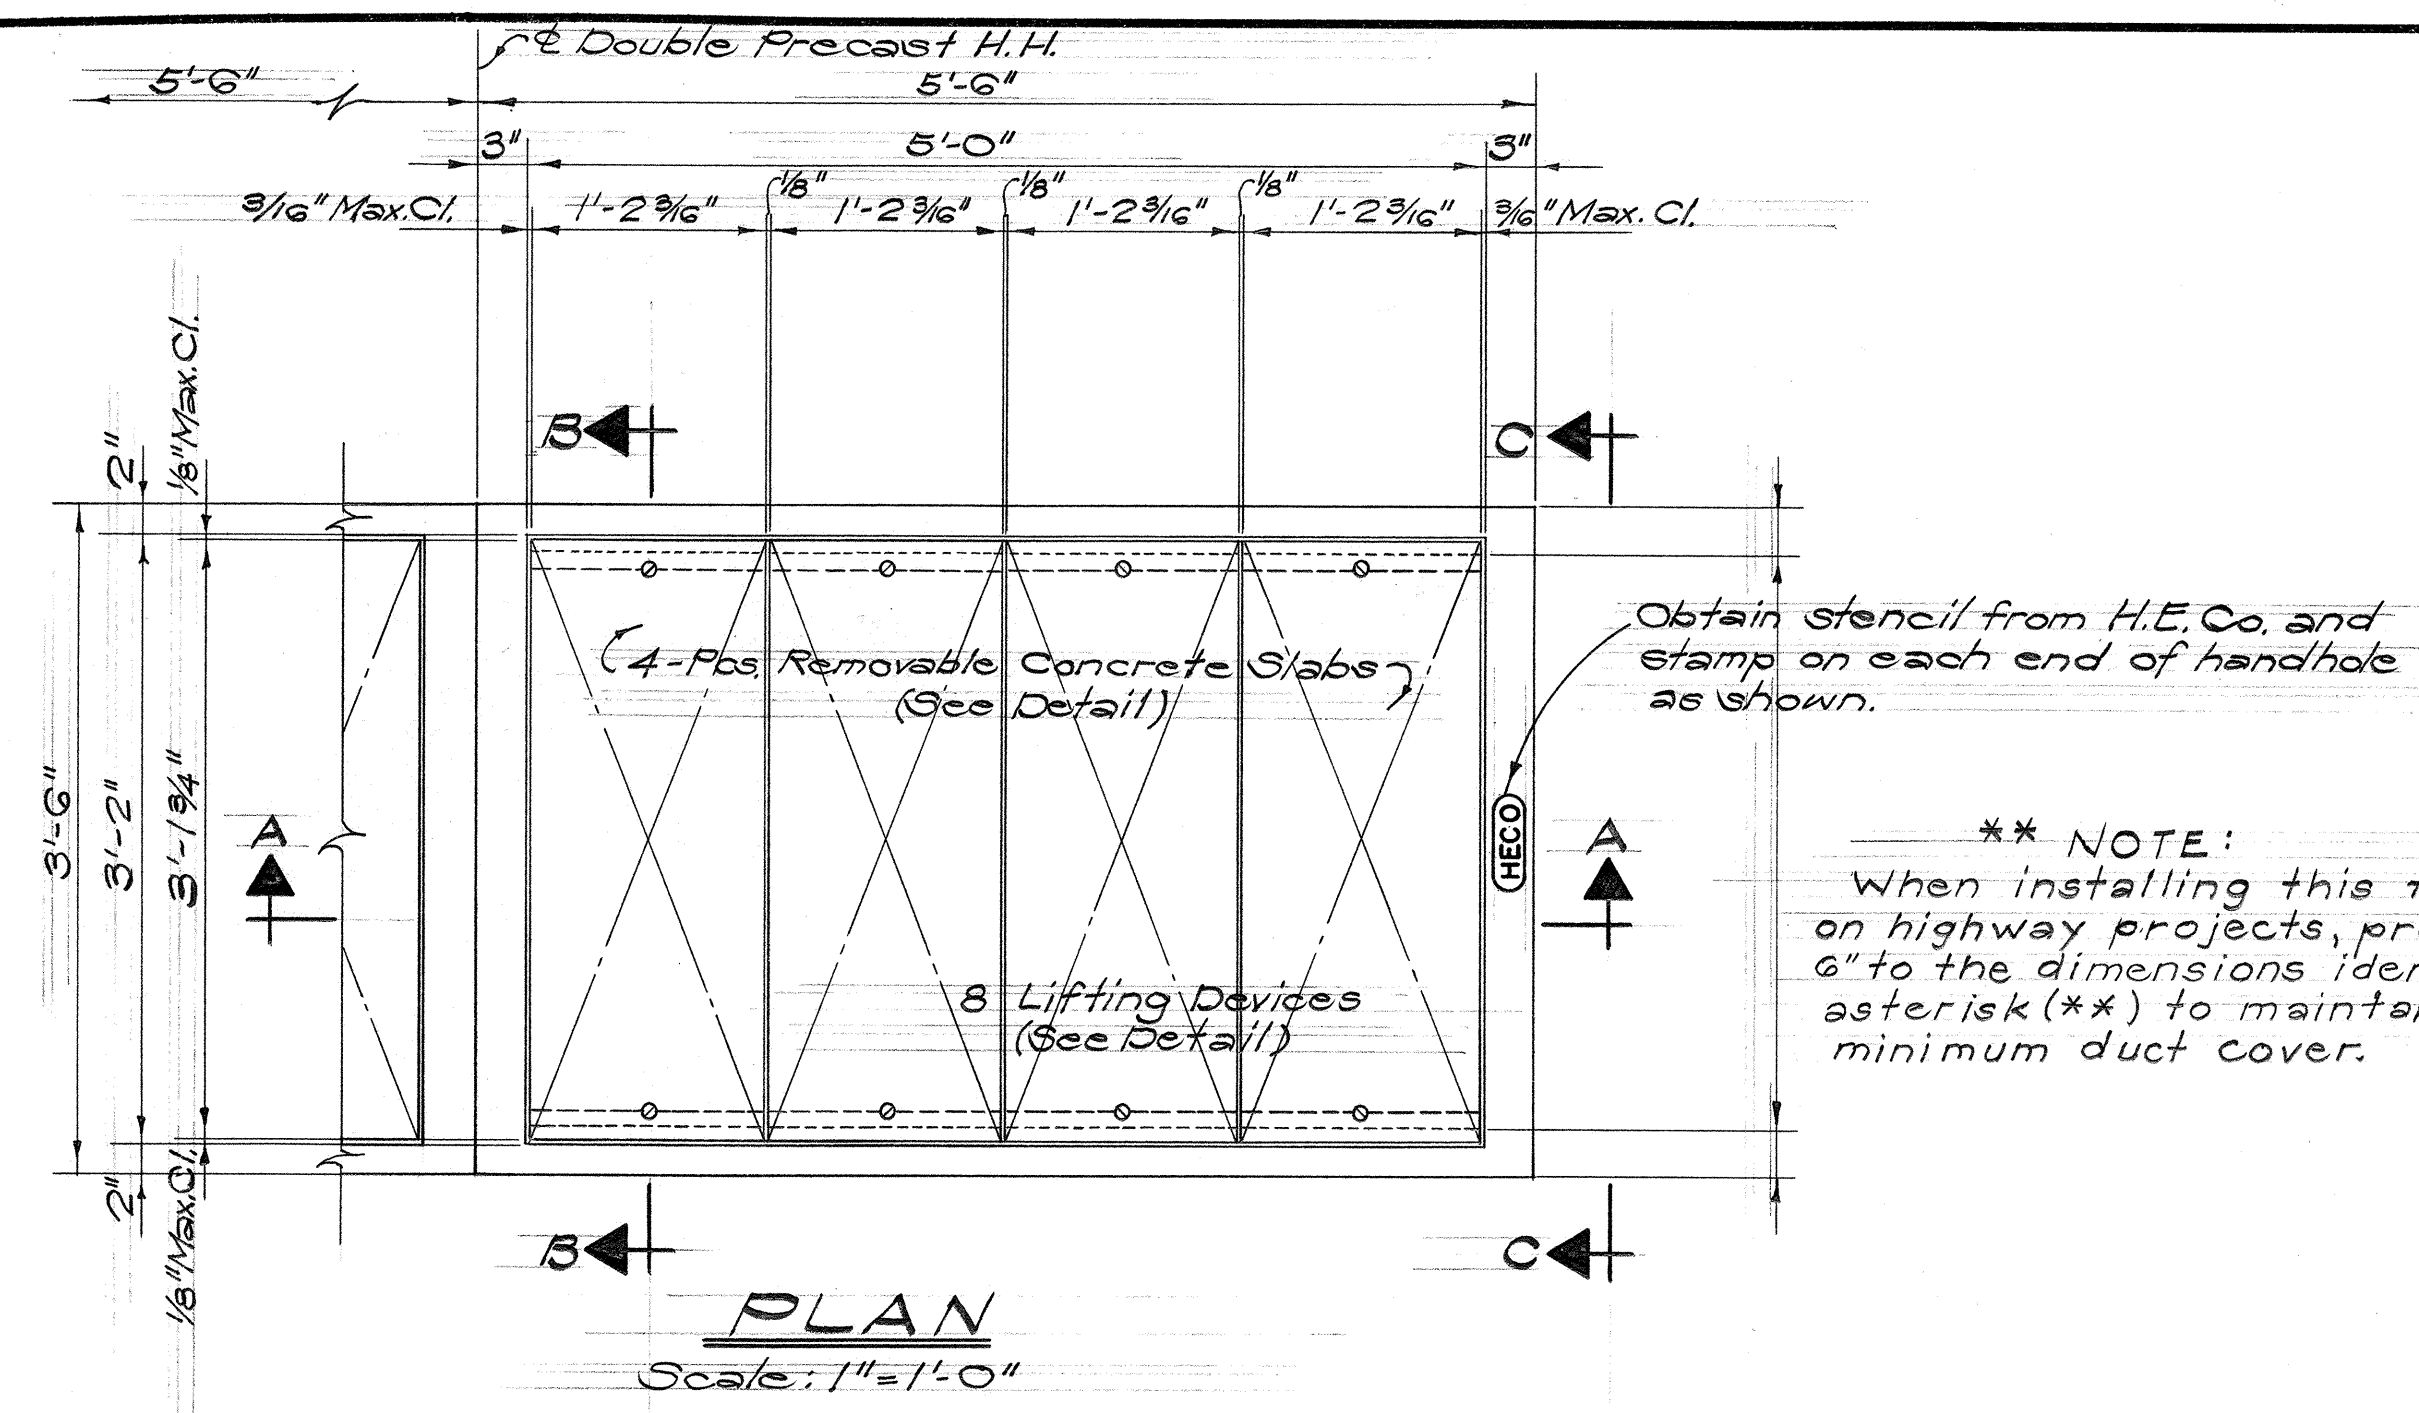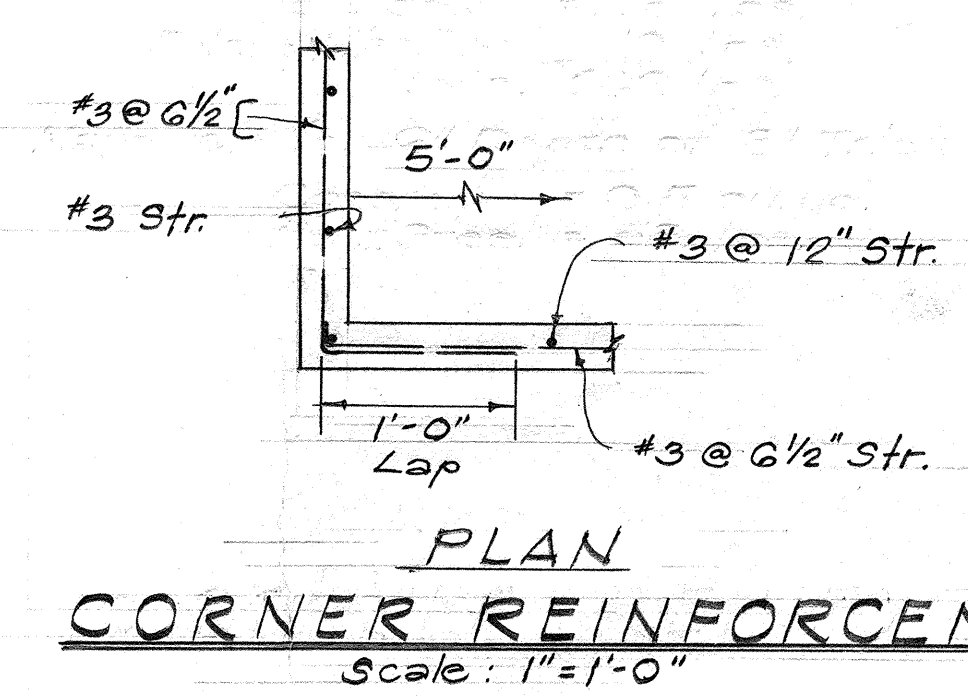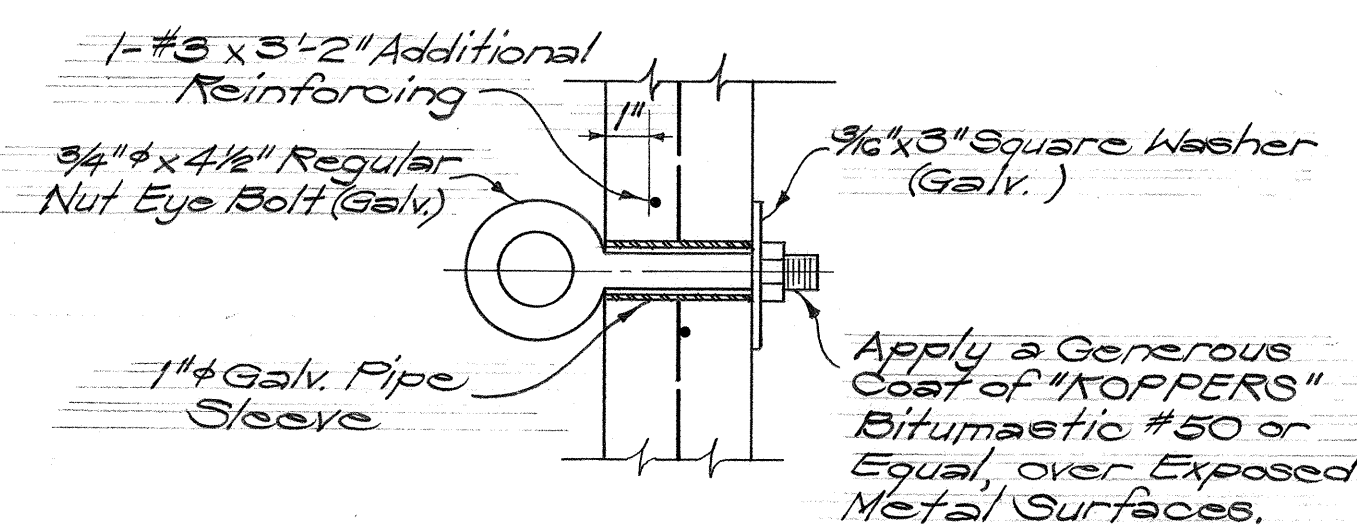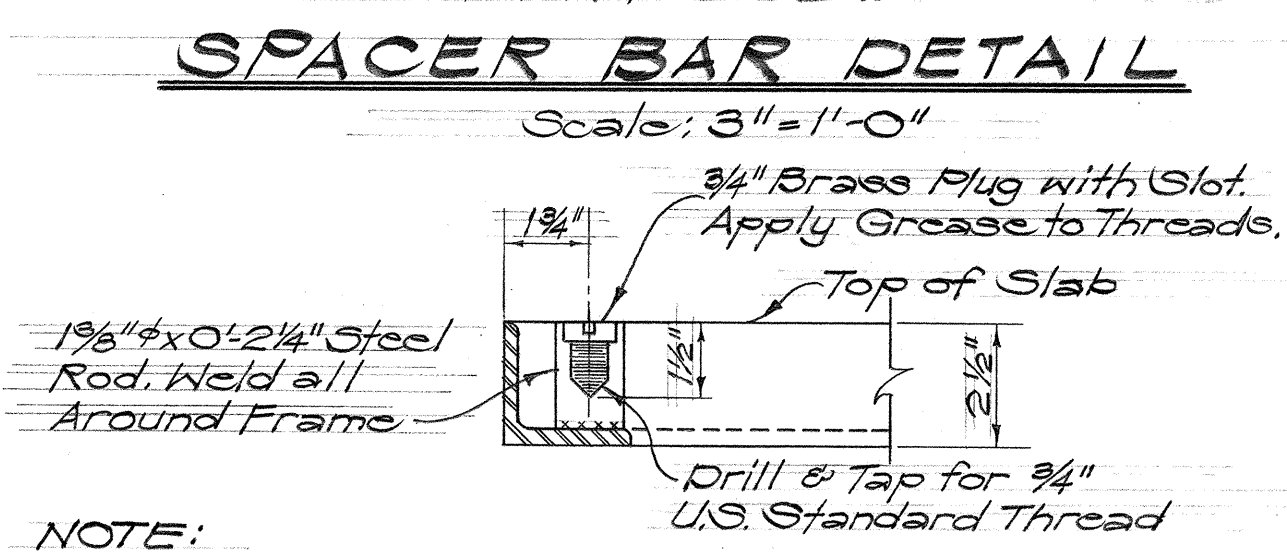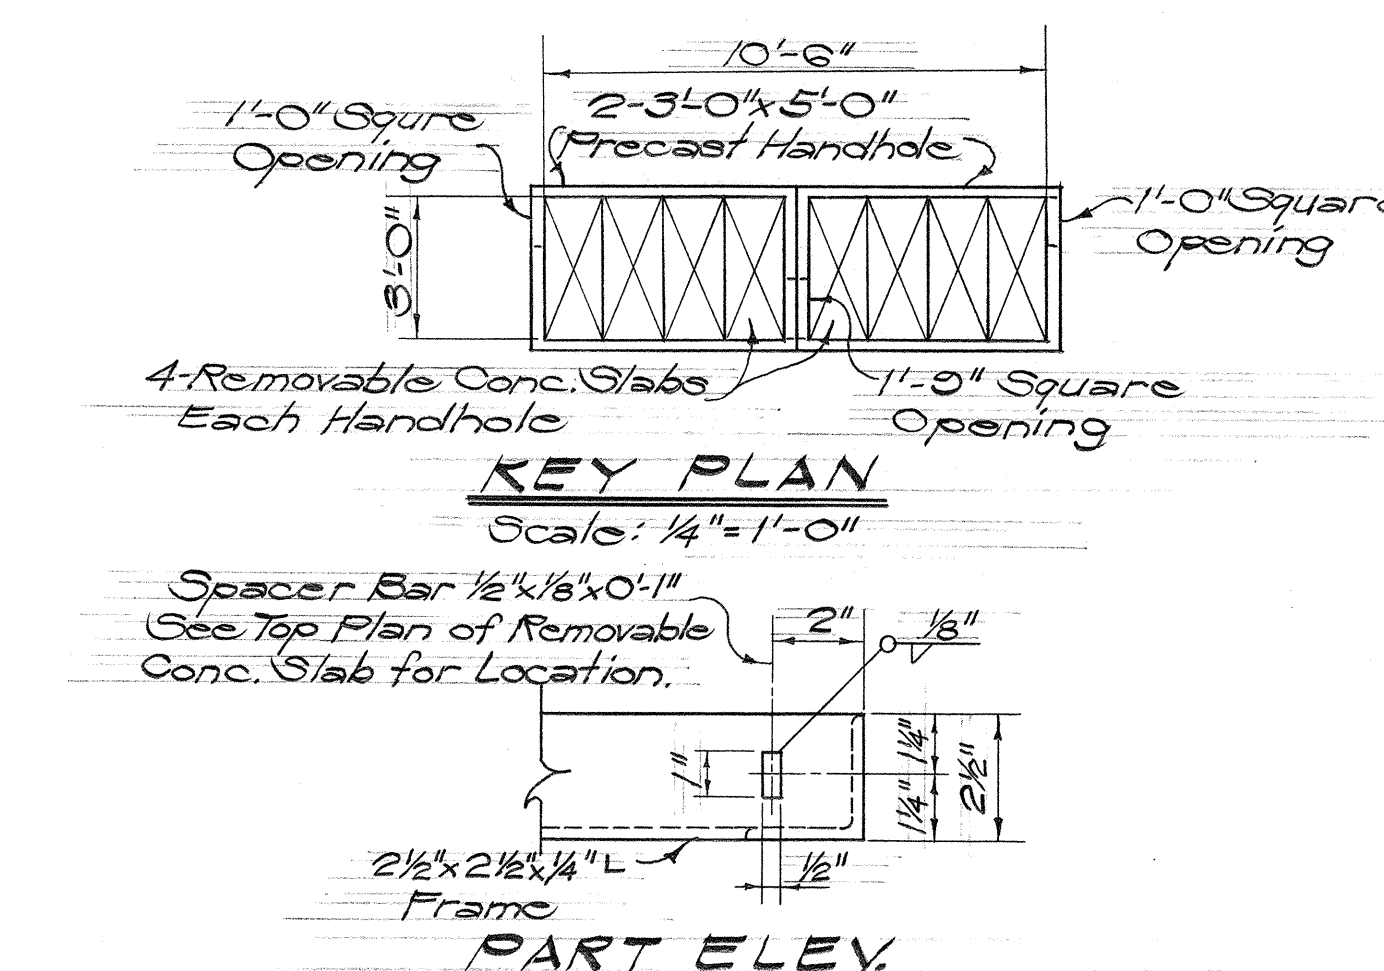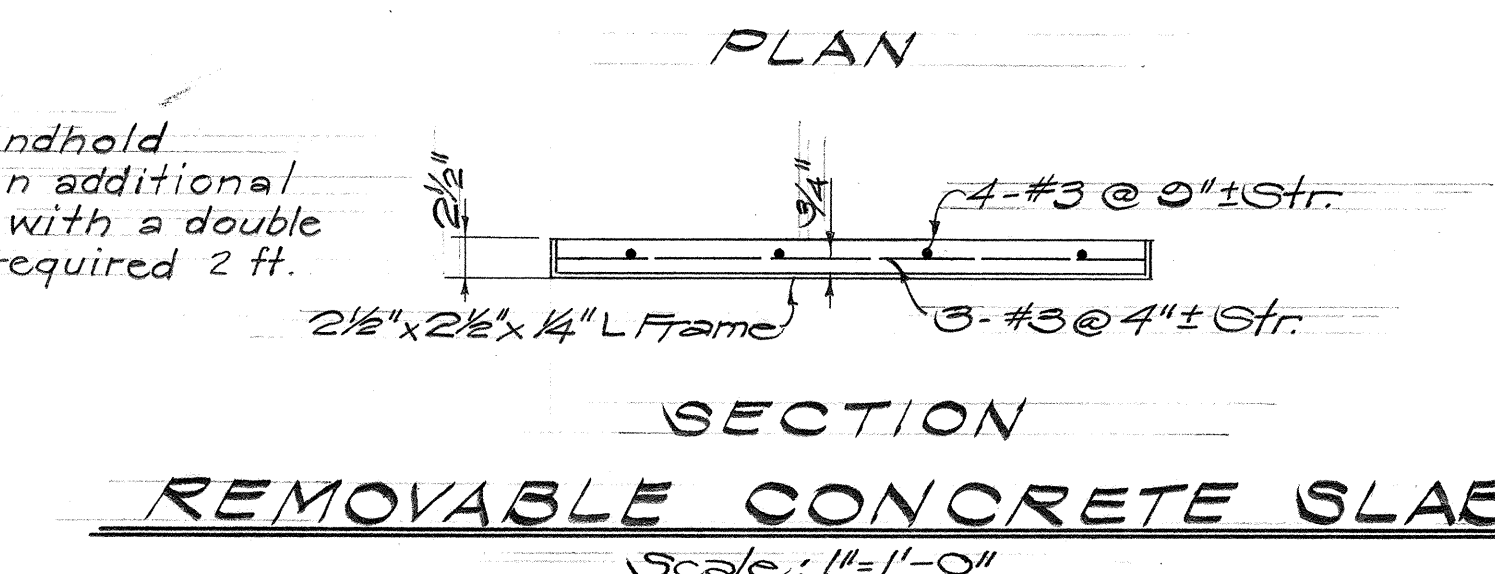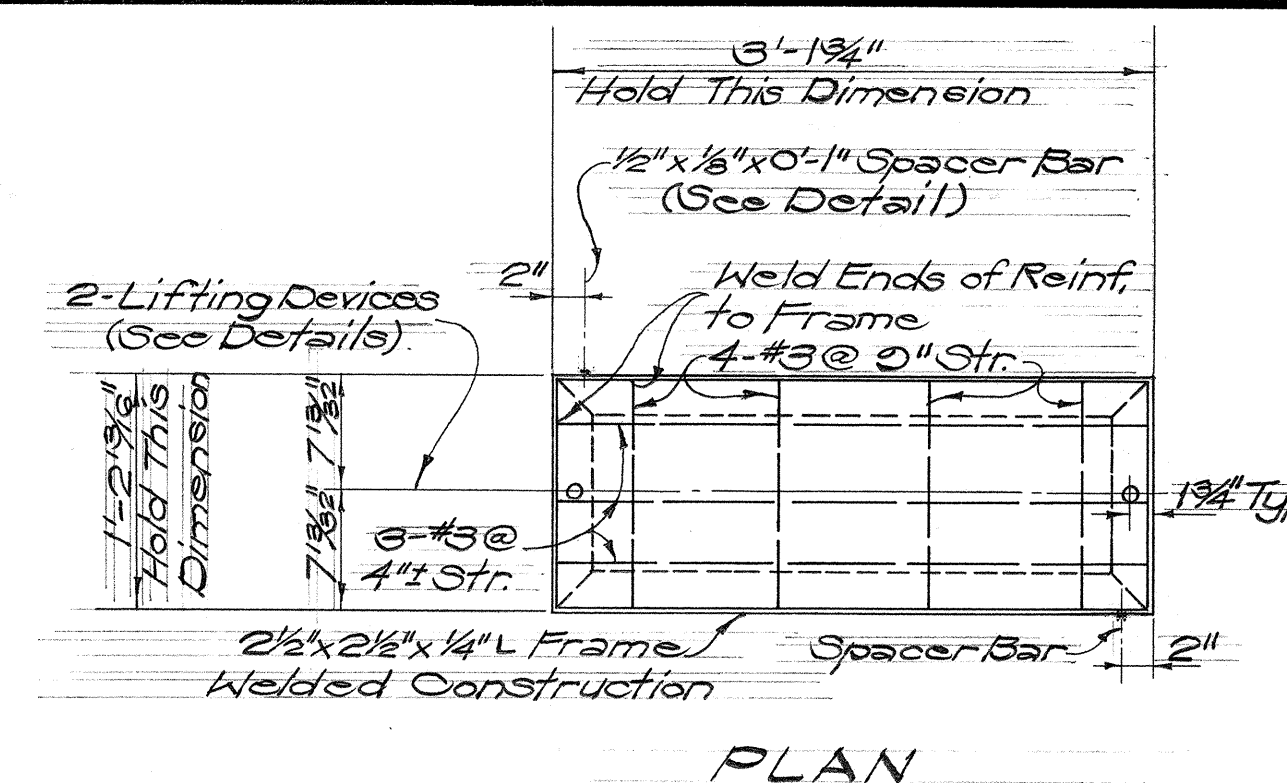

NOTE "X" IMPORTANT
Maximum clearances between removable concrete cover slabs and concrete opening at the supports must be kept. Concrete Contractor shall measure cover slab steel frame after fabrication to obtain proper clearances. Any variation in clearances shall be corrected to the satisfaction of the Engineer at Contractor's expense.

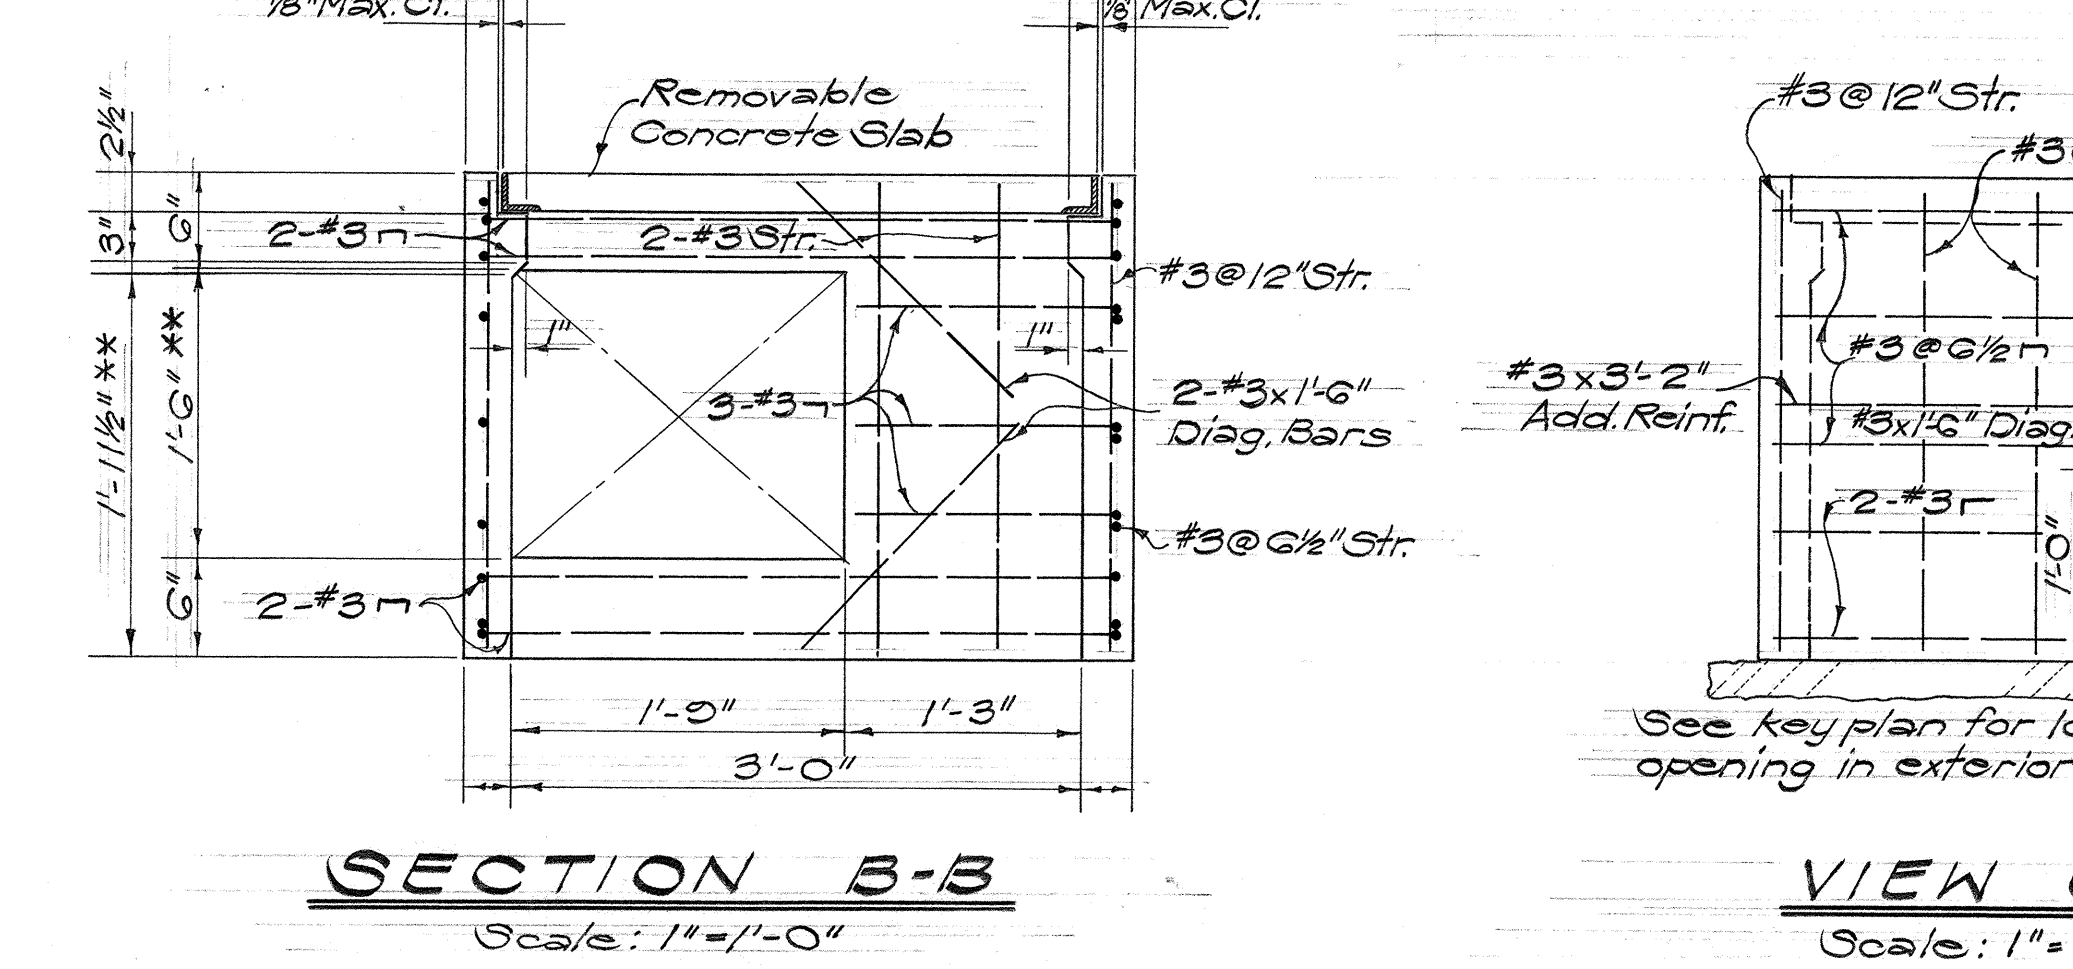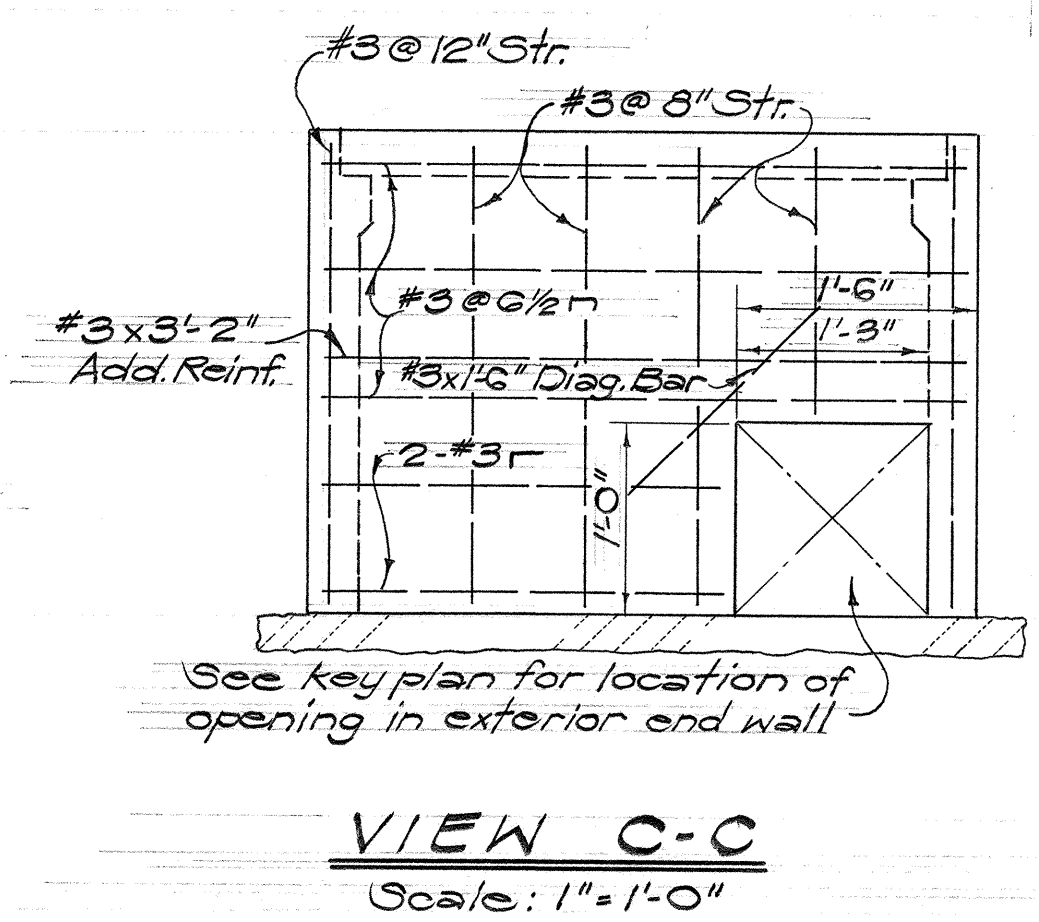

PRINTED ON NO. 1000H CLEARPRINT

