



ELECTRICAL SYMBOL LIST

---	CONDUIT OR DUCTLINE, NEW
⊖	DUCTLINE INDICATOR SEE DUCT SECTION
EP2	NEW ELECTRIC POLE BY CONTRACTOR
	POLE LENGTH POLE FRAMING POLE CLASS
	45 3 F.1 P.3
○	EXISTING ELECTRIC POLE TO REMAIN
⊗	EXISTING ELECTRIC POLE TO BE REMOVED
L-10 30-3	INDICATES GUY LENGTH NEW GUY AND ANCHOR DEADMAN & ROD INDICATES 30 FT CLASS 3 WOOD POLE
ETC	EXISTING TELEPHONE DUCTLINE OR CABLE
ETC	EXISTING TELEPHONE CABLE TO BE REMOVED BY HTCO
○	NEW ELECTRIC POLE BY UTILITY COMPANY POST HOLE BY CONTRACTOR
○	NEW ELECTRIC MANHOLE
□	NEW SPUR PIT FOR HAWAIIAN TELEPHONE CO. TRANS-PACIFIC CABLE.
□	NEW FULBOX FOR H.T.CO. HT.CO #433 T.B. FURNISHED BY H.T.CO. INSTALLED BY CONTRACTOR
---	STUD & CAP CONDUIT
----	NEW OVERHEAD ELECTRIC PRIMARY BY CONTRACTOR
—E—	EXISTING ELECTRIC PRIMARY OVERHEAD
E	EXISTING ELECTRIC PRIMARY OVERHEAD TO BE REMOVED
L-15	DEAD END LENGTH - 15'

NOTE: CONDUIT BENDS FOR UTILITY CO. POLES FURNISHED BY UTILITY CO., INSTALLED BY CONTRACTOR.

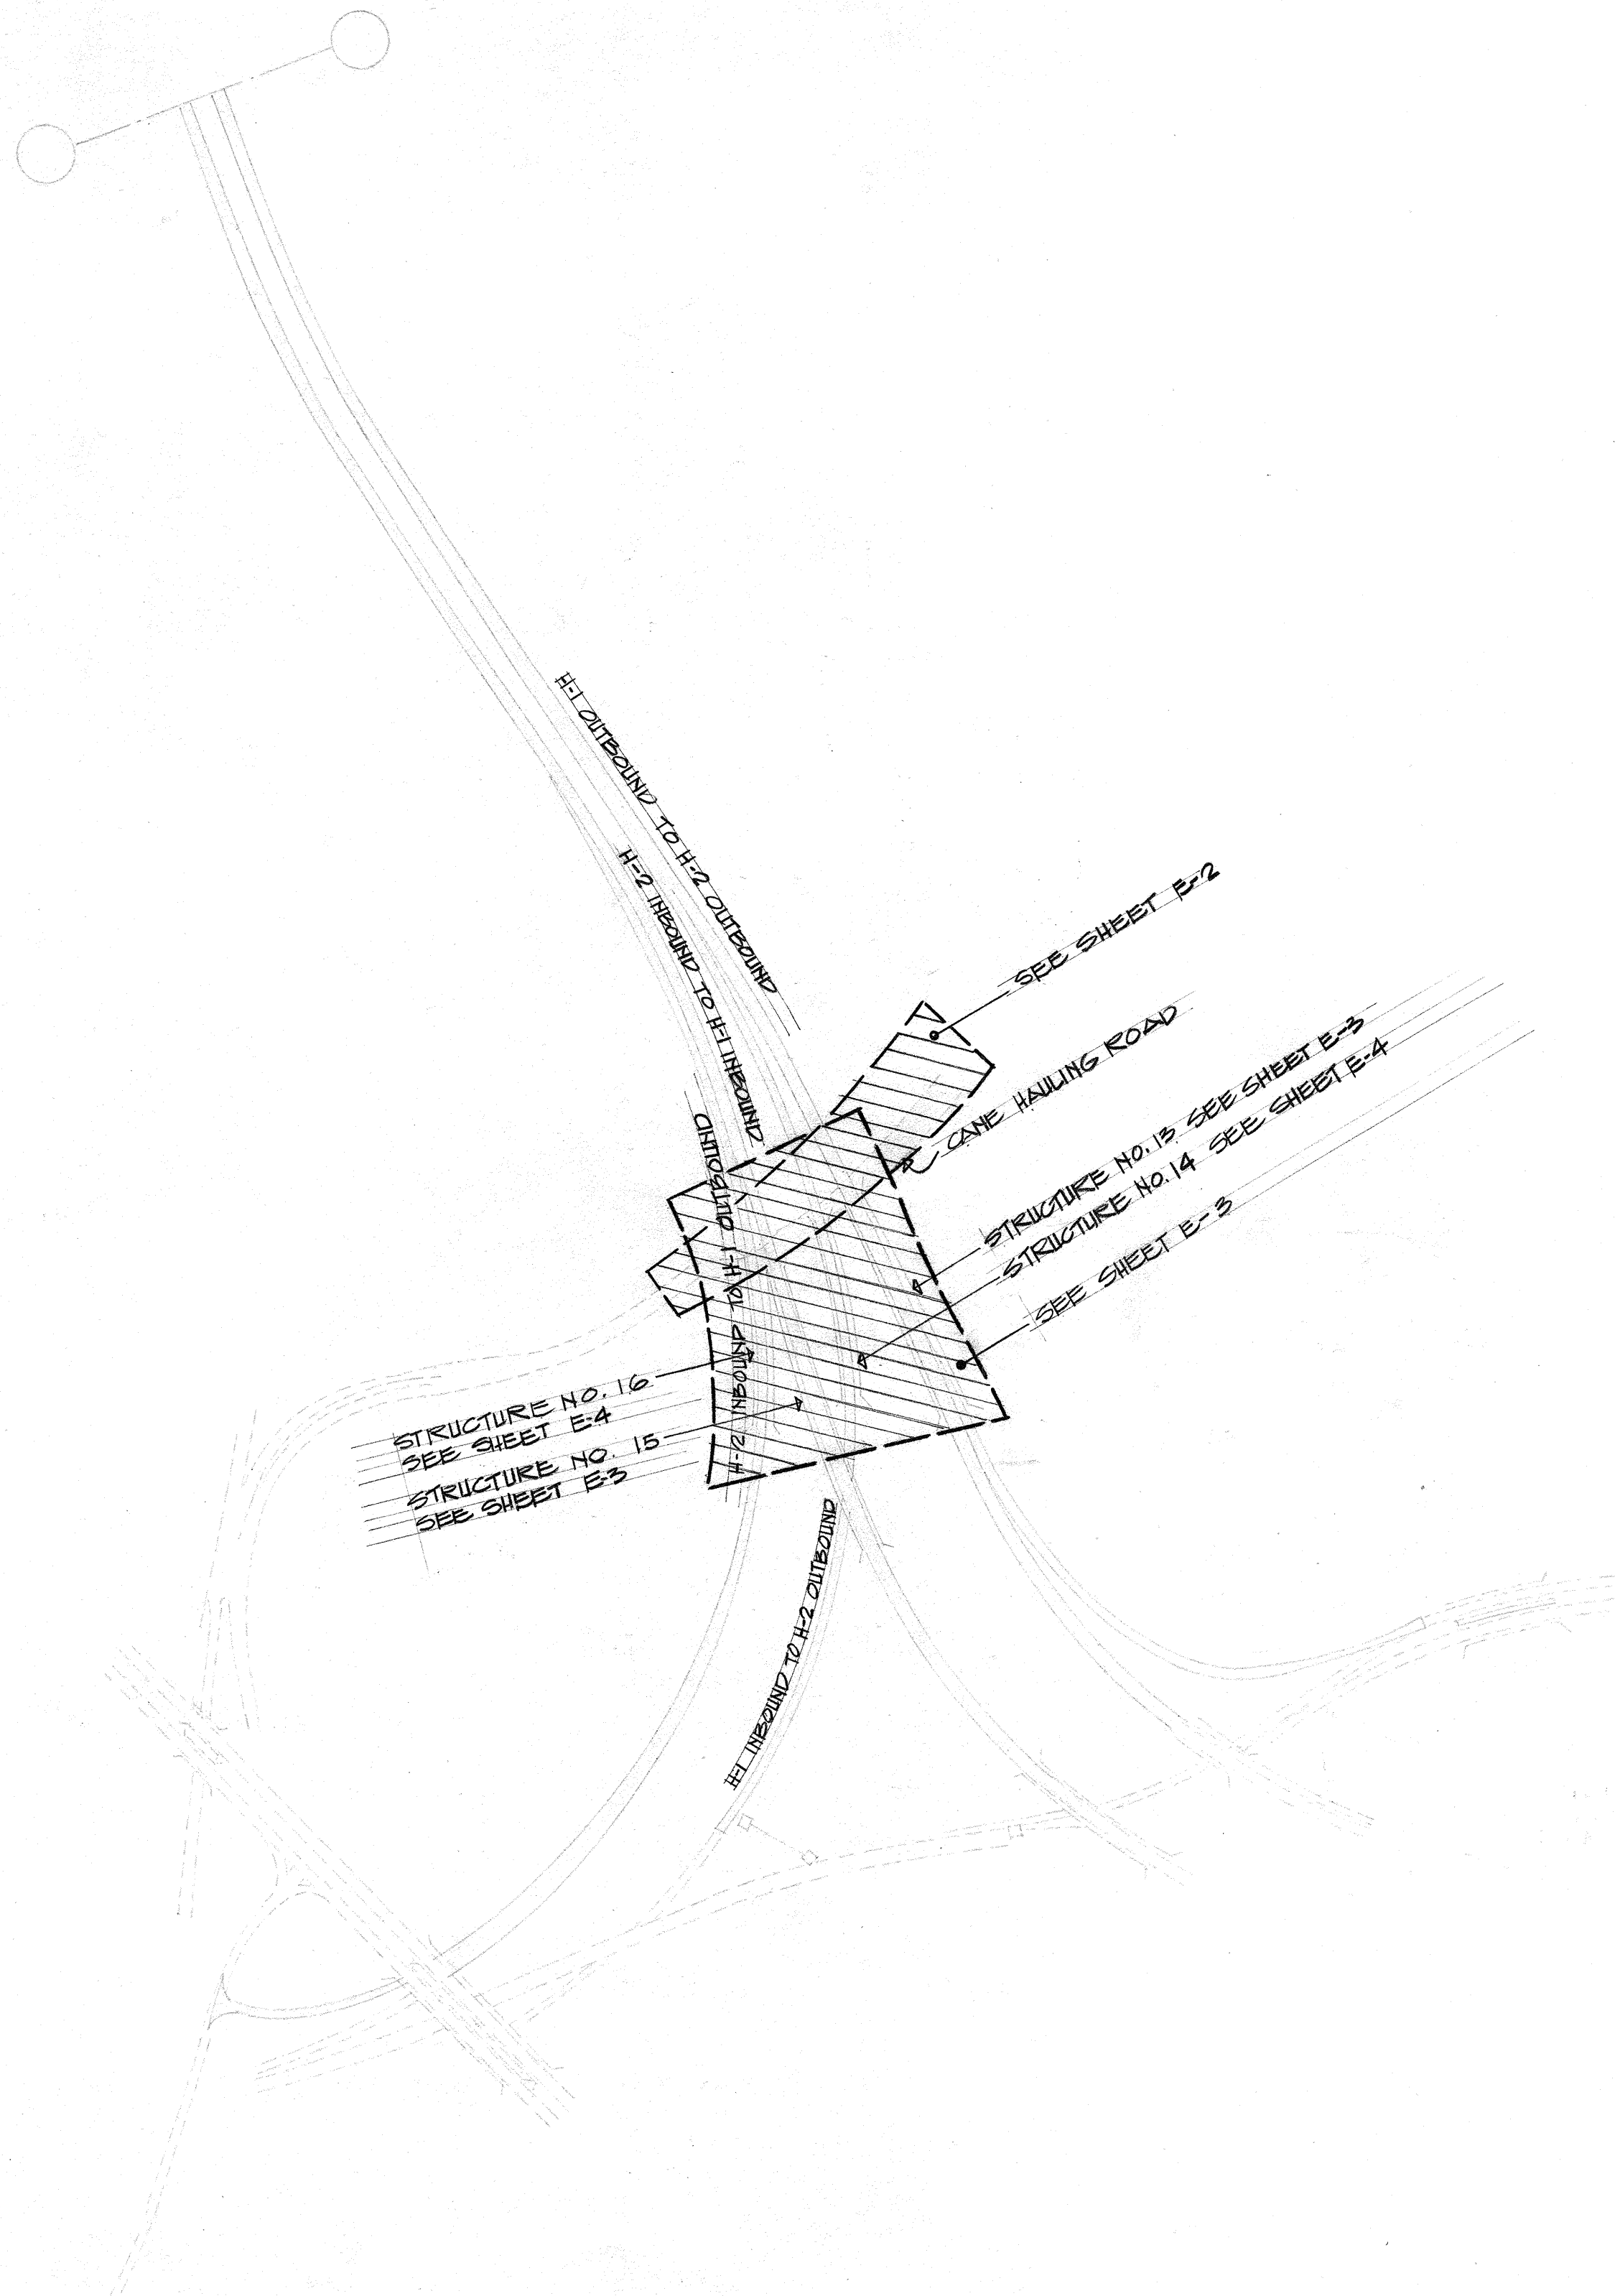

ELECTRICAL SITE PLAN
SCALE: 1" = 300'

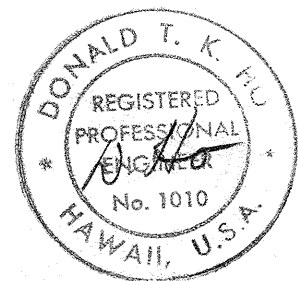

THIS WORK WAS PREPARED BY ME OR UNDER MY SUPERVISION.


STATE OF HAWAII
DEPARTMENT OF TRANSPORTATION
HIGHWAYS DIVISION
WAIKAWA INTERCHANGE

ELECTRICAL SITE PLAN
SYMBOL LIST

F.A.I. Proj. No. I-H-1 (75): 3
Scale: As shown Date:


SHEET No. E-1 OF 17 SHEETS

FED. ROAD DIST. NO.	STATE	FED. AID PROJ. NO.	FISCAL YEAR	SHEET NO.	TOTAL SHEETS
HAWAII	HAW.	I-HI-1(75):8 I-HI-1(14):8	1969	C.O. ADD. 52 S-1	181

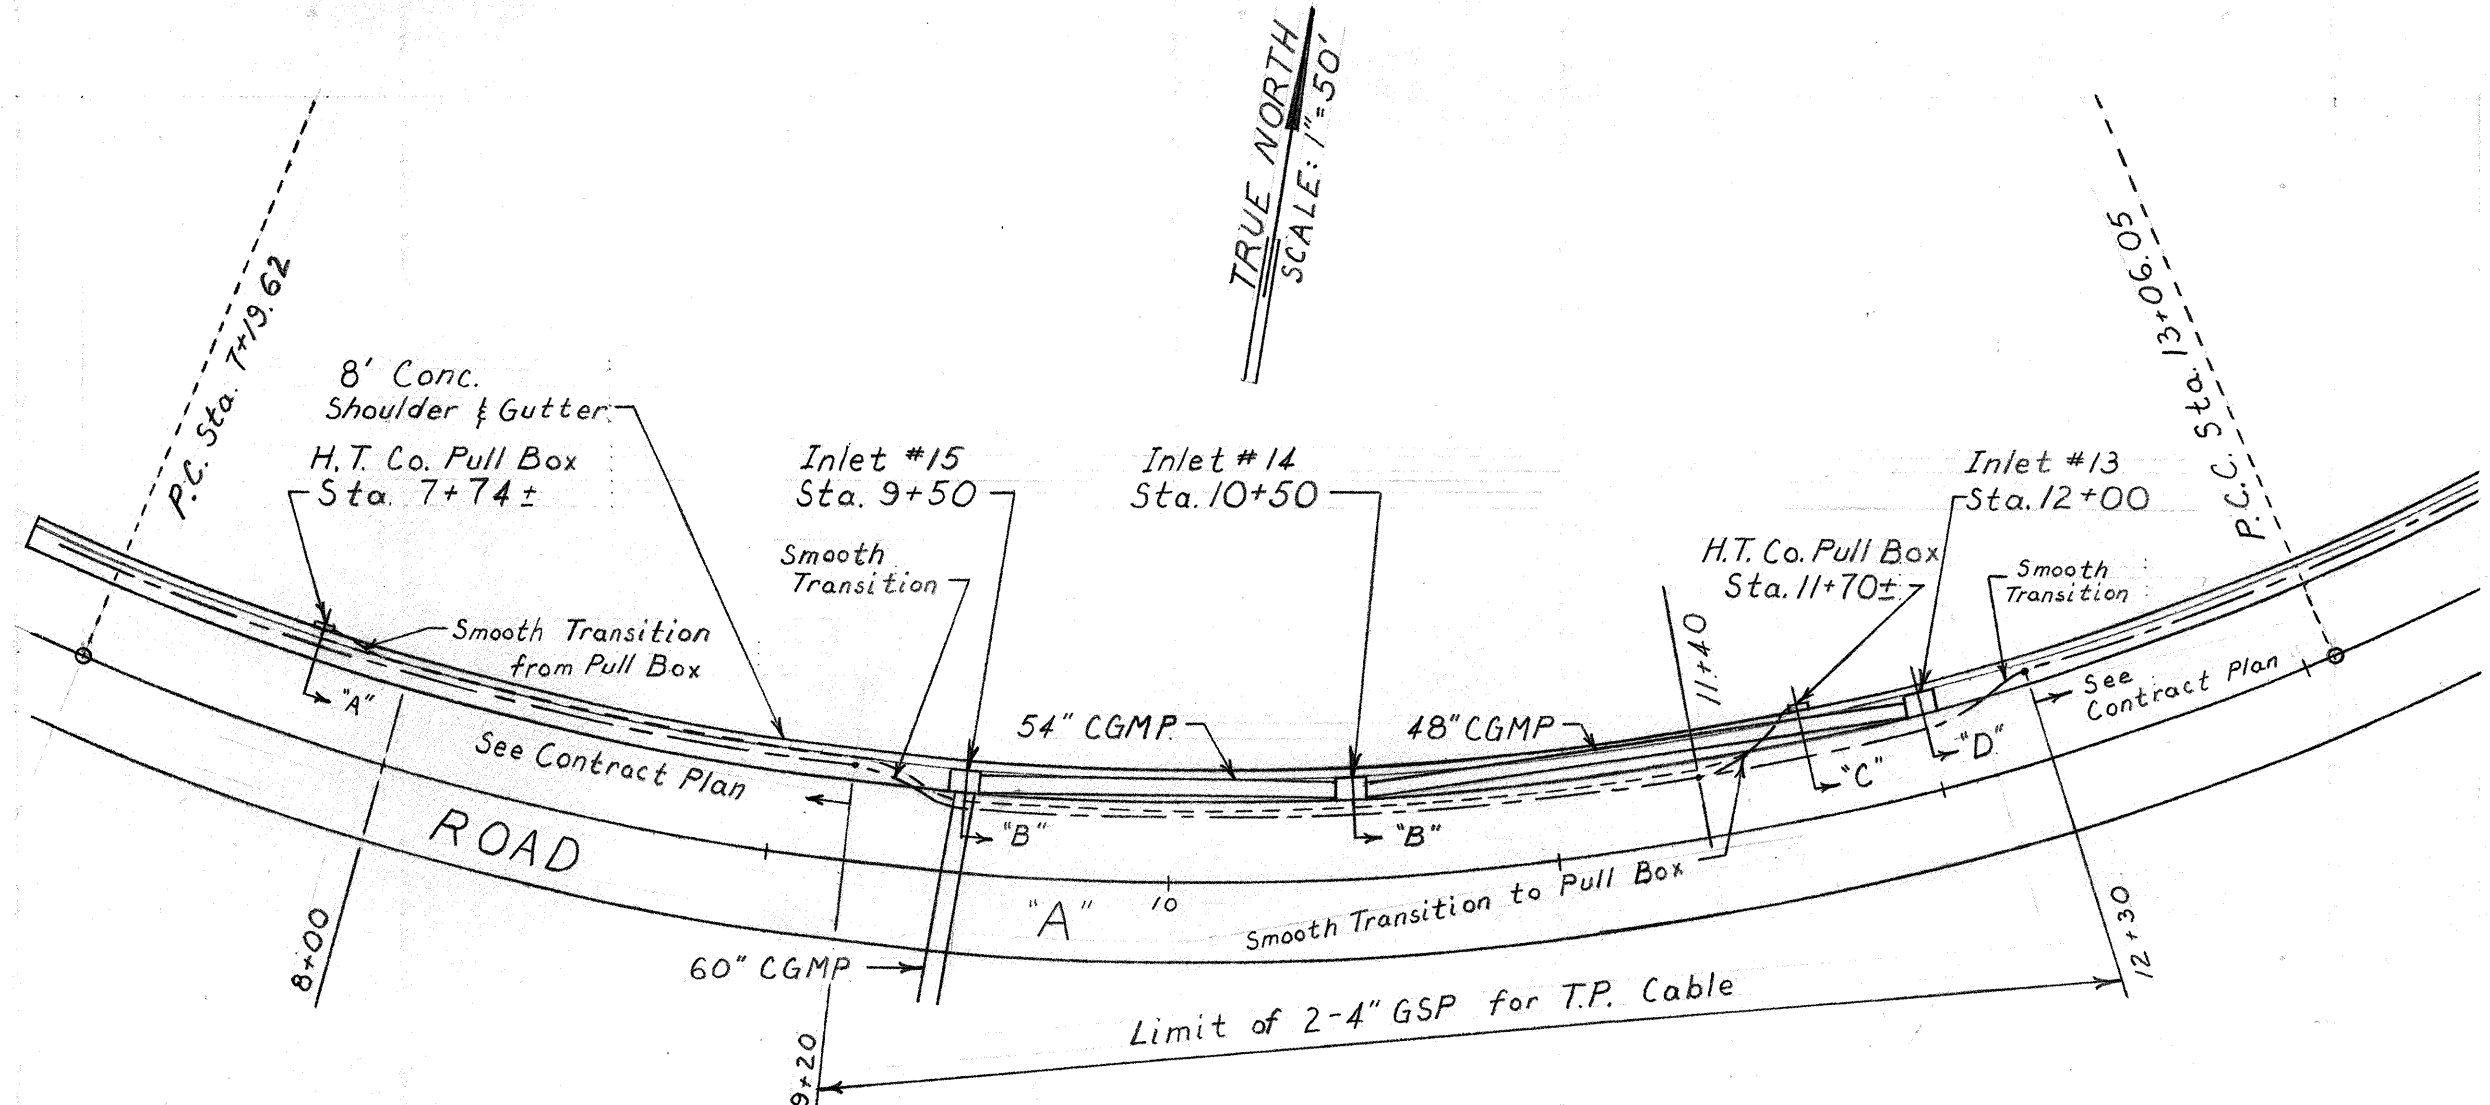


CONTRACT CHANGE ORDER #8
TELEPHONE REVISIONS
ALONG ROAD "A"
F.A.I.P. No. I-HI-1(75):8
Date: 9/8/70

LEGEND
--- T.P. Cable
--- 2-4" Conduits
Encased in Concrete

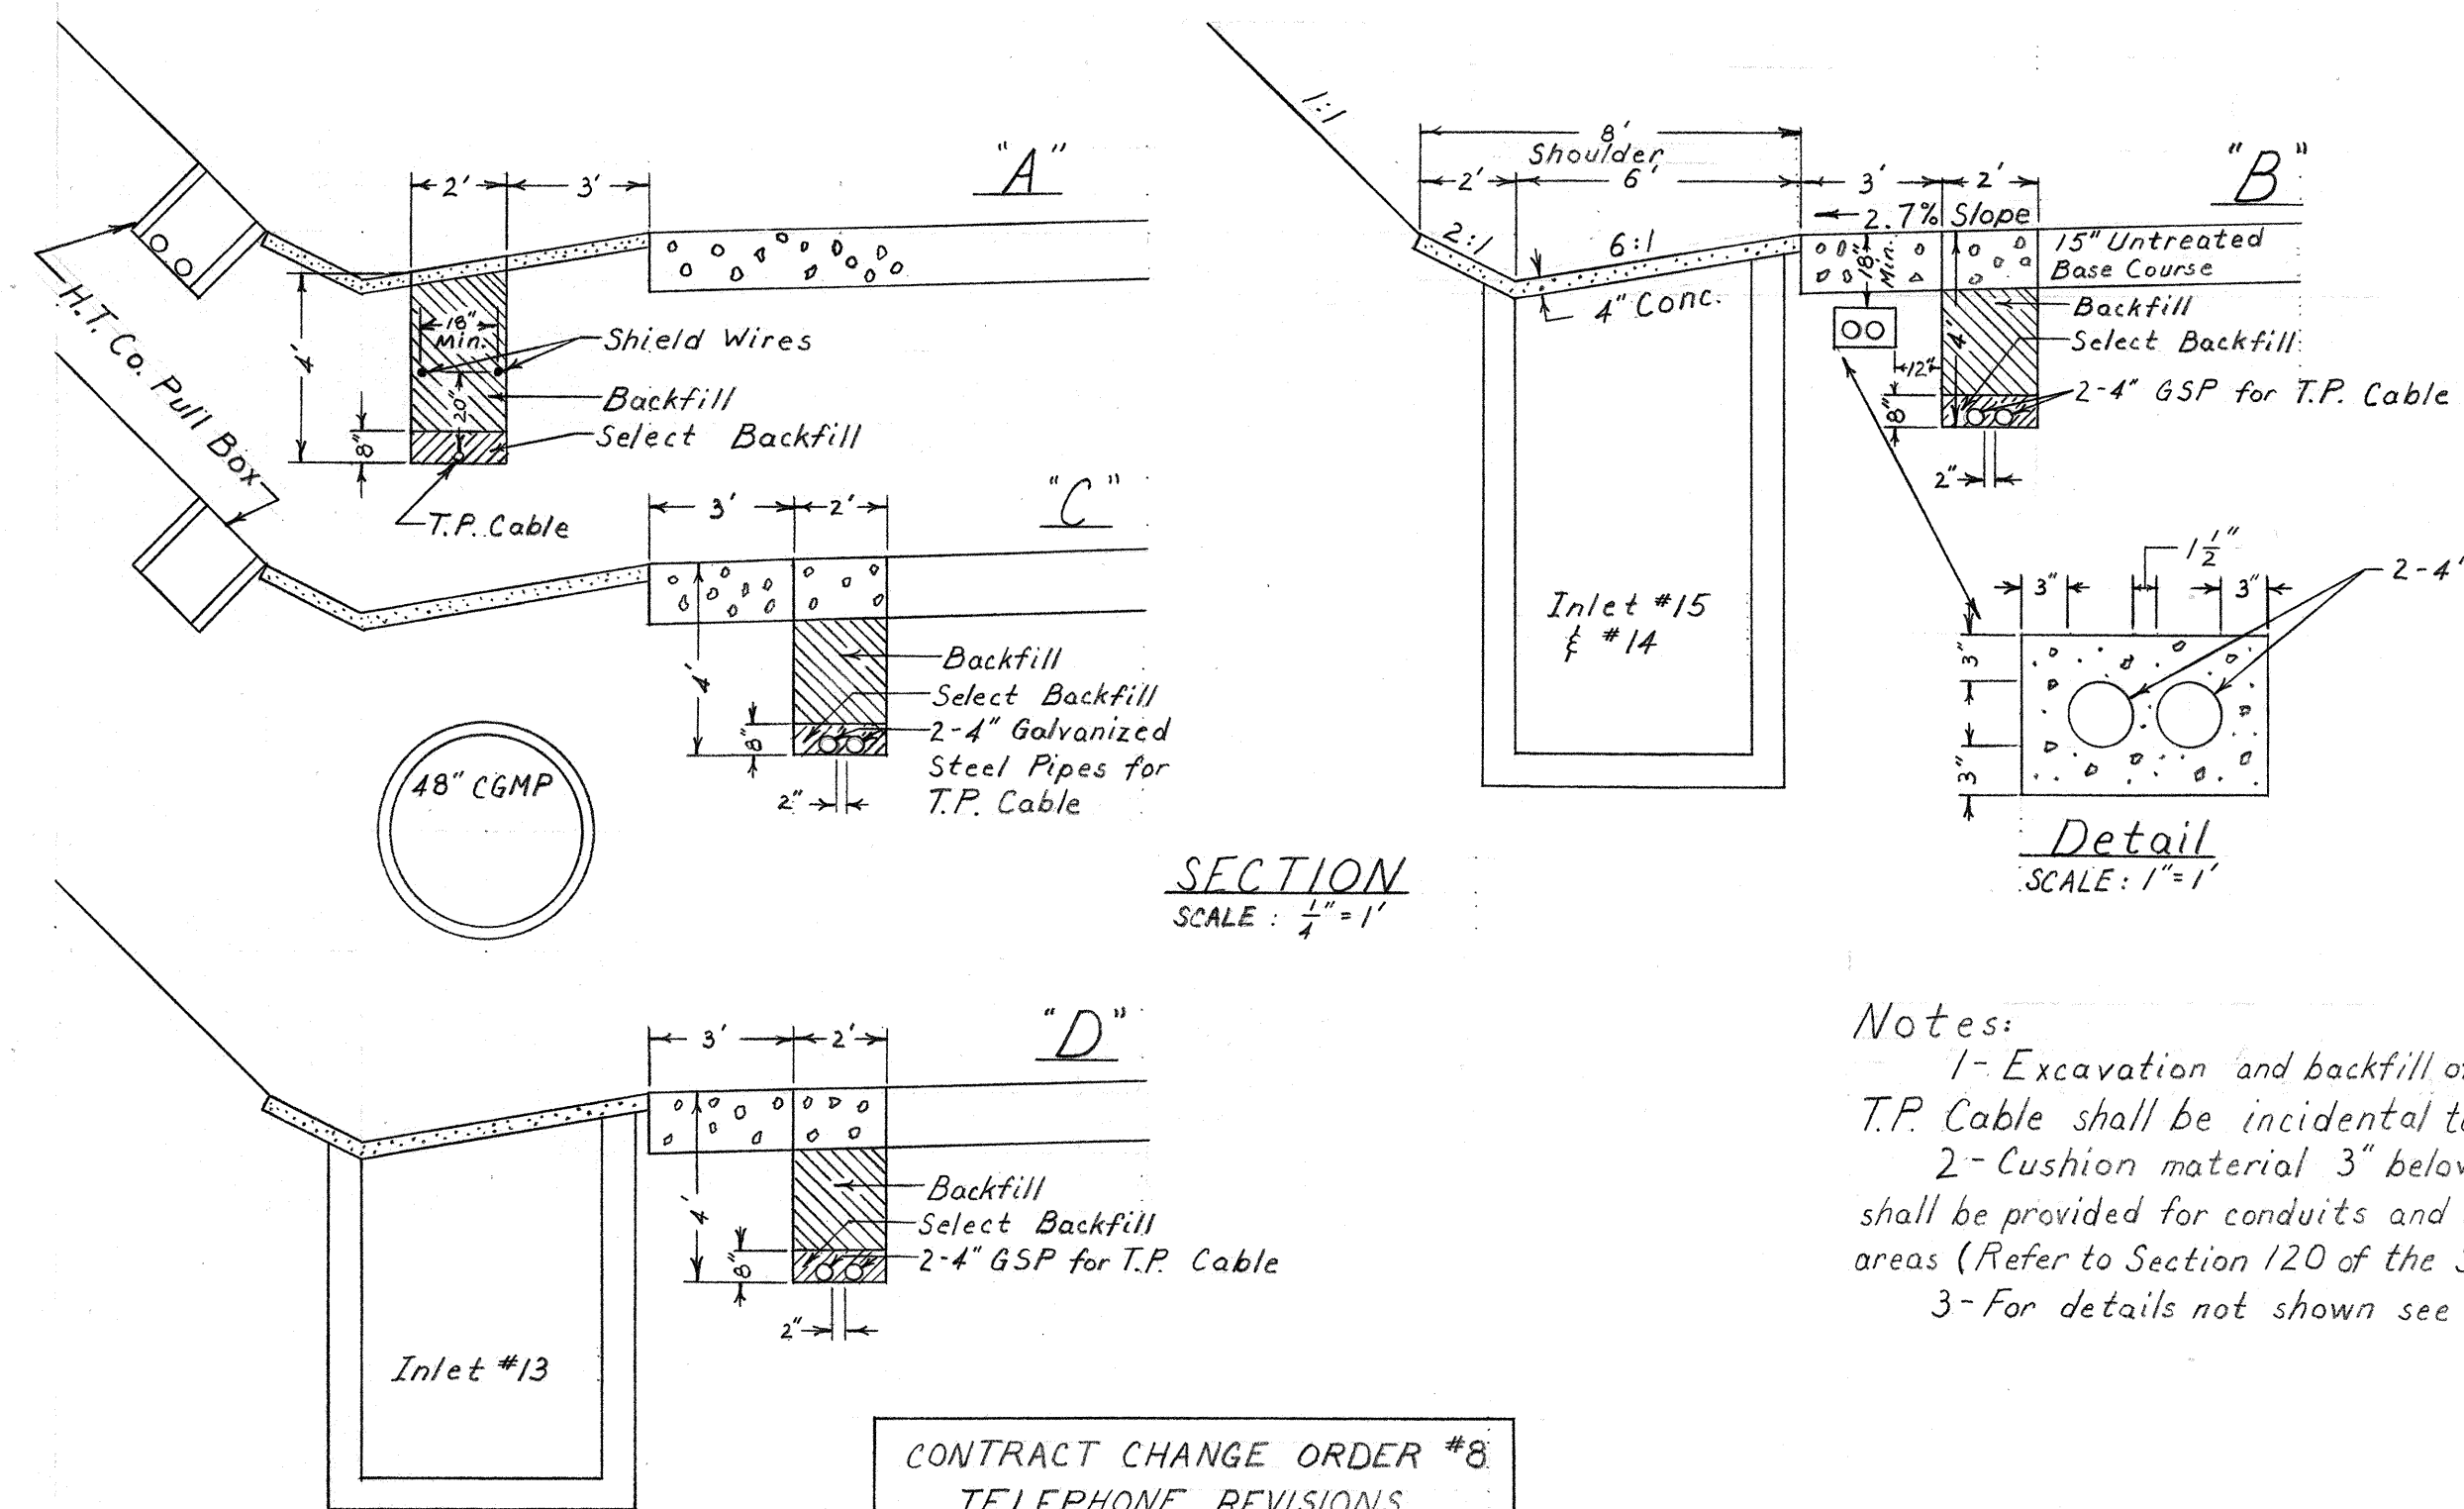

CONTRACT CHANGE ORDER #8
TELEPHONE REVISIONS
ALONG ROAD "A"
F.A.I.P. No. I-HI-1(75):8
Date: 9/8/70

Notes:
1- Excavation and backfill of 2-4" GSP for T.P. Cable shall be incidental to Item No. 120. 3571.
2- Cushion material 3" below invert grade shall be provided for conduits and cables in rocky areas (Refer to Section 120 of the Special Provisions)
3- For details not shown see Contract Plans.

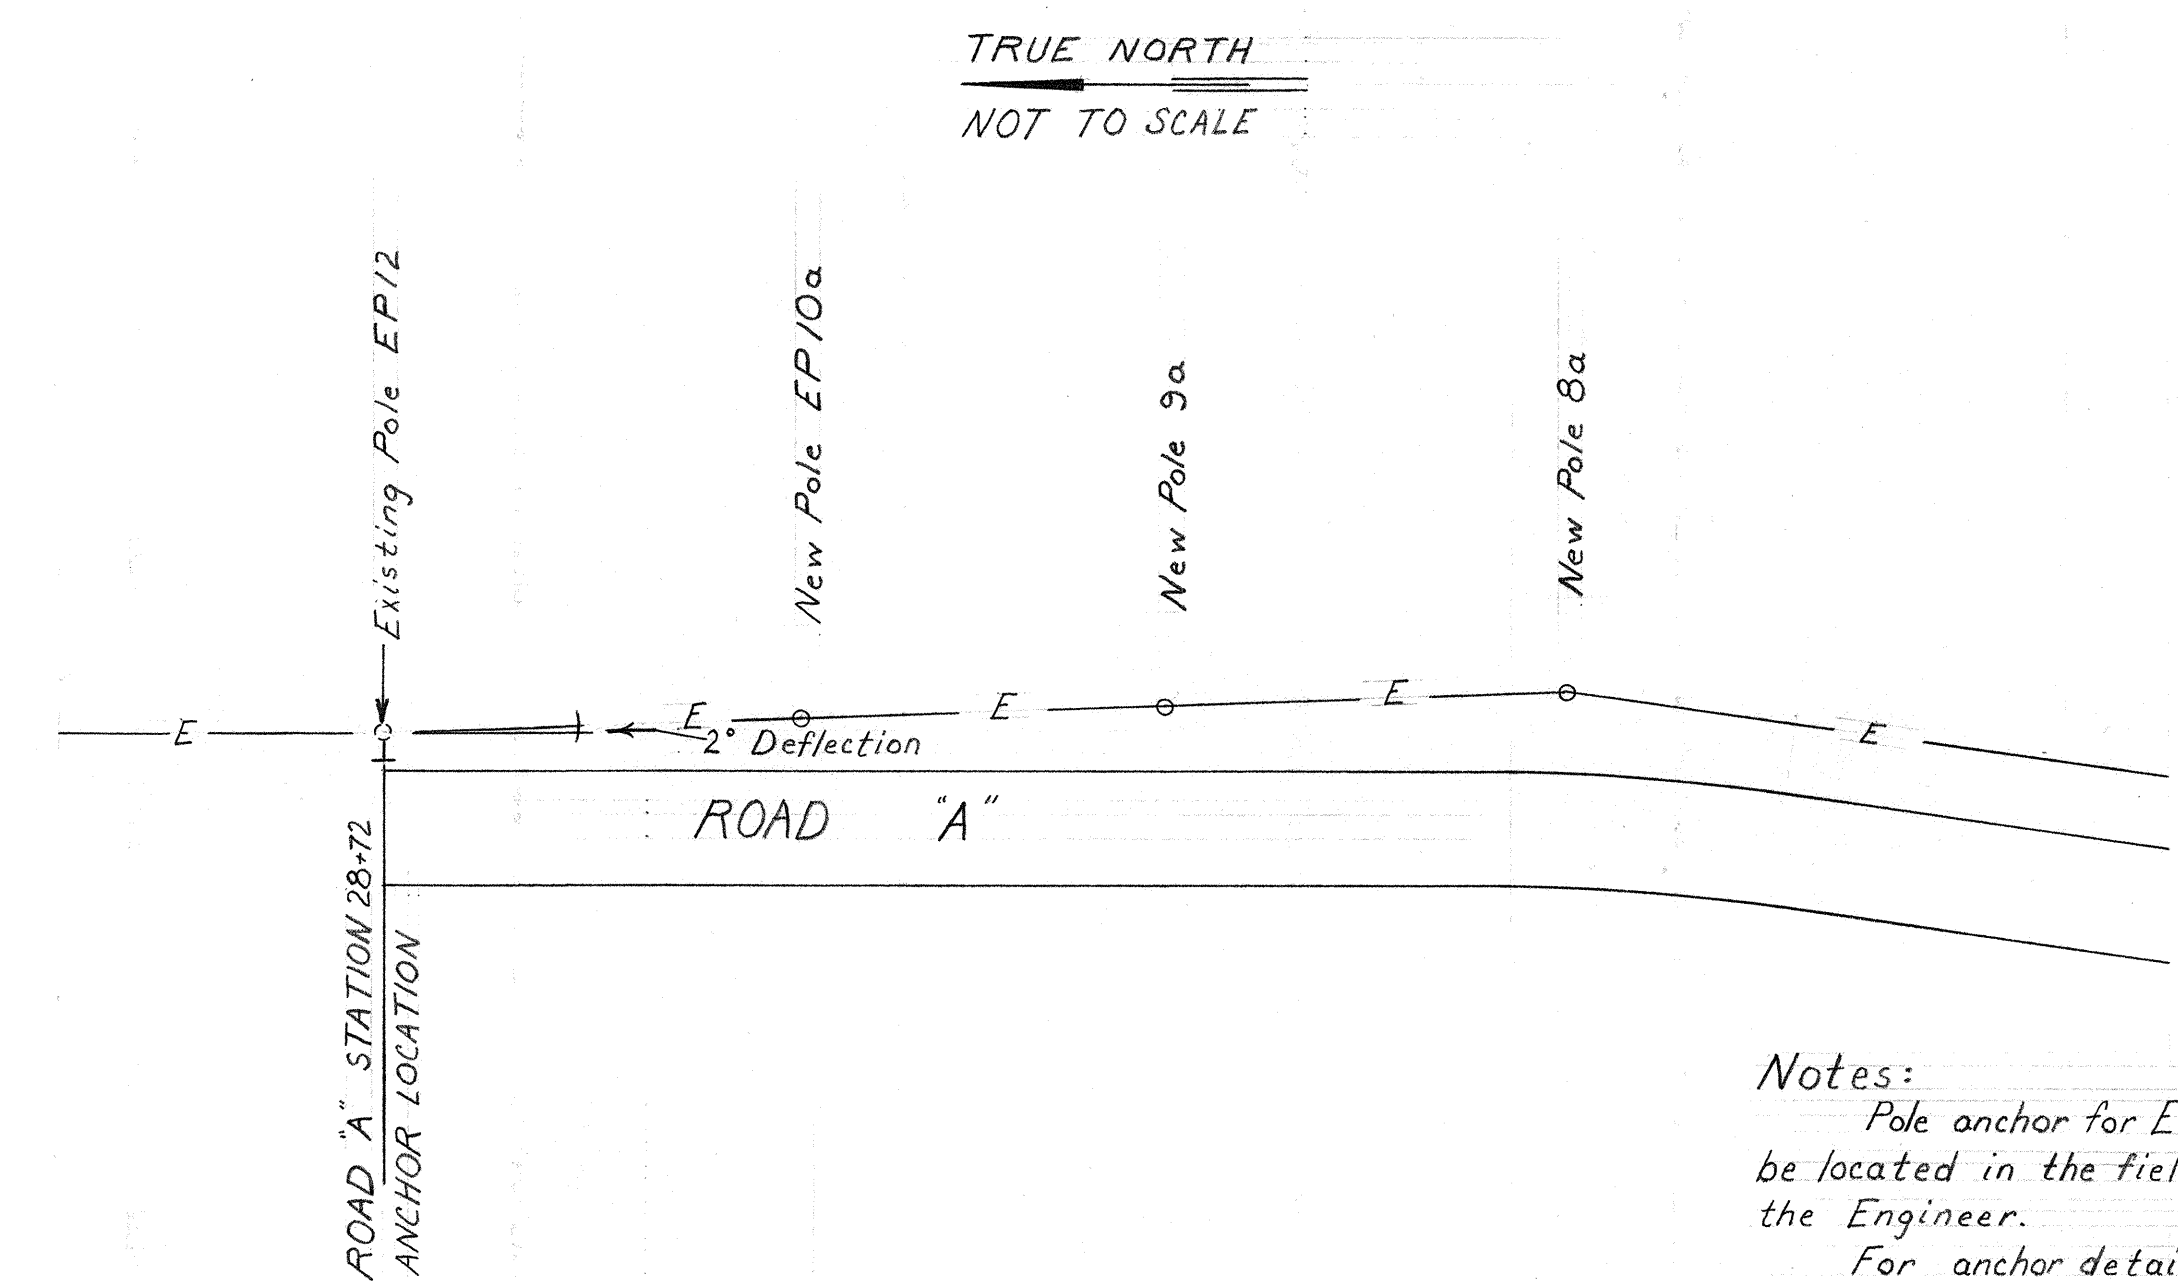

CONTRACT CHANGE ORDER #17
ELECTRICAL REVISIONS
ALONG ROAD "A"
F.A.I.P. No. I-HI-1(14):8
Date: March 1971

Notes:
Pole anchor for EP12 to be located in the field by the Engineer.
For anchor detail see Plan Sheet No. 55.


STATE OF HAWAII
DEPARTMENT OF TRANSPORTATION
HIGHWAYS DIVISION
CONTRACT CHANGE ORDERS
#8 & #17
F.A.I.P. No. I-HI-1(75):8
F.A.I.P. No. I-HI-1(14):8
SCALE: AS SHOWN

SHEET NO. OF SHEETS


C.O. ADD. 52 S-1

SURVEY PLOTTED BY	DATE
DRAWN BY	"
DESIGNED BY	"
CHECKED BY	"
ORIGINAL PLAN	No.
NOTE BOOK	No.

FED. ROAD DIST. NO.	STATE	FED. AID PROJ. NO.	FISCAL YEAR	SHEET NO.	TOTAL SHEETS
HAWAII	HAW.	2-11-1(19)8	1969	53	181

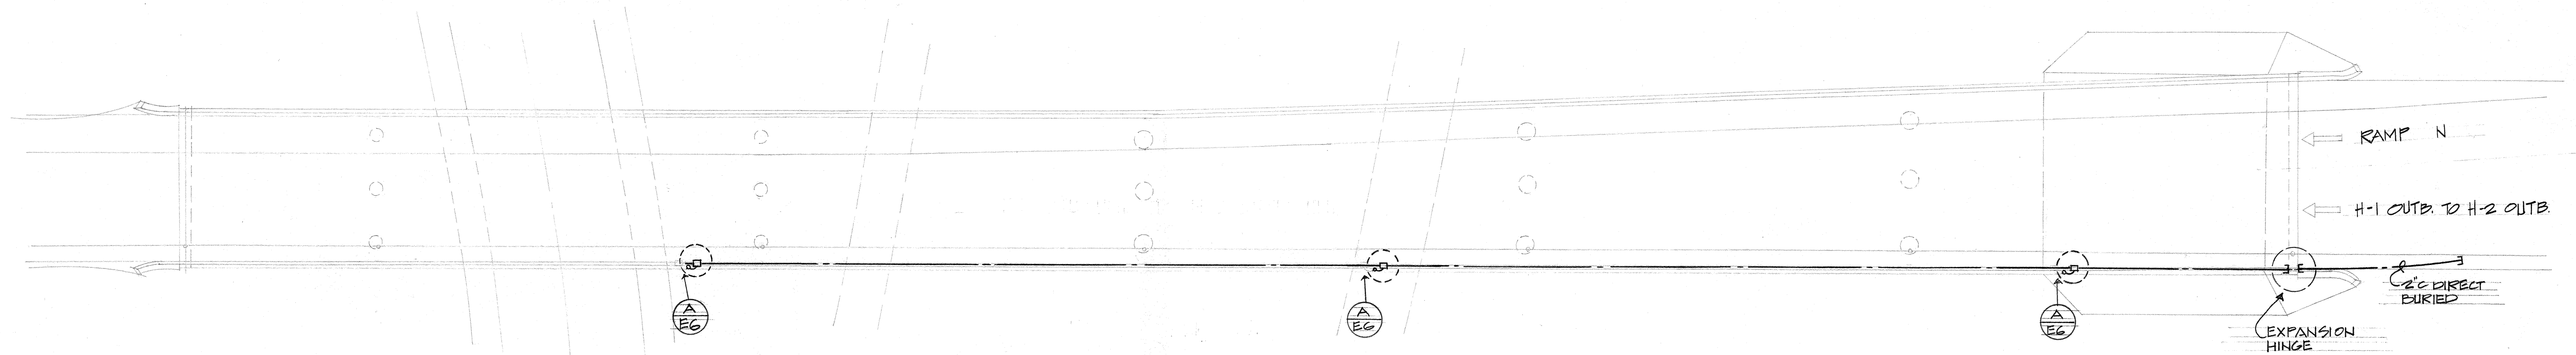


RACEWAY PLAN - STRUCTURE NO. 13
SCALE: 1" = 20'-0"

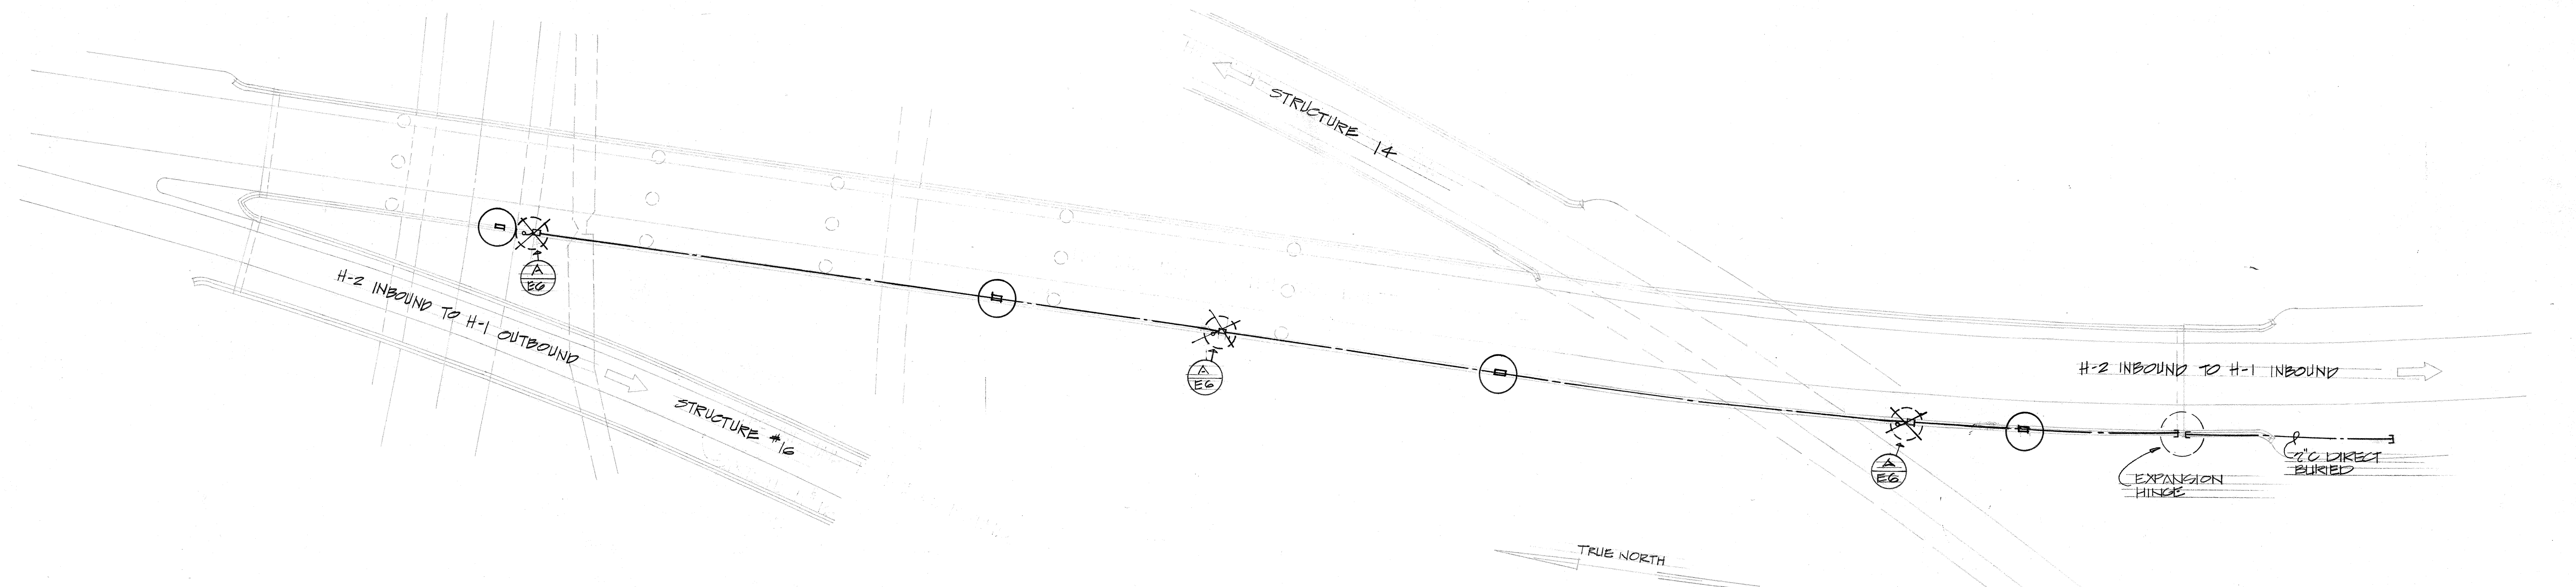

RACEWAY PLAN - STRUCTURE NO. 15
SCALE: 1" = 20'-0"

DESIGNED BY	DATE
DRAWN BY	
CHECKED BY	
NOTED BY	
QUANTITIES BY	
REVISIONS BY	
NO.	

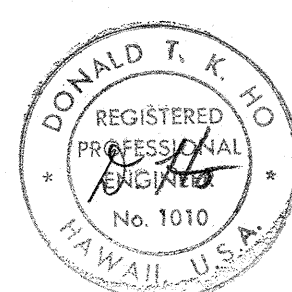

THIS WORK WAS PREPARED BY
ME OR UNDER MY SUPERVISION.


STATE OF HAWAII
DEPARTMENT OF TRANSPORTATION
HIGHWAYS DIVISION
WAIKAWA INTERCHANGE

STRUCTURES No. 13 & 15
ELECTRICAL RACEWAY PLAN


P.A.I. Proj. No. I-H-1(15): B
Scale: As shown Date:

SHEET No. E-3 OF 17 SHEETS


FED. ROAD DIST. NO.	STATE	FED. AID PROJ. NO.	FISCAL YEAR	SHEET NO.	TOTAL SHEETS
HAWAII	HAW.	[H-17] 10	1979	54	151

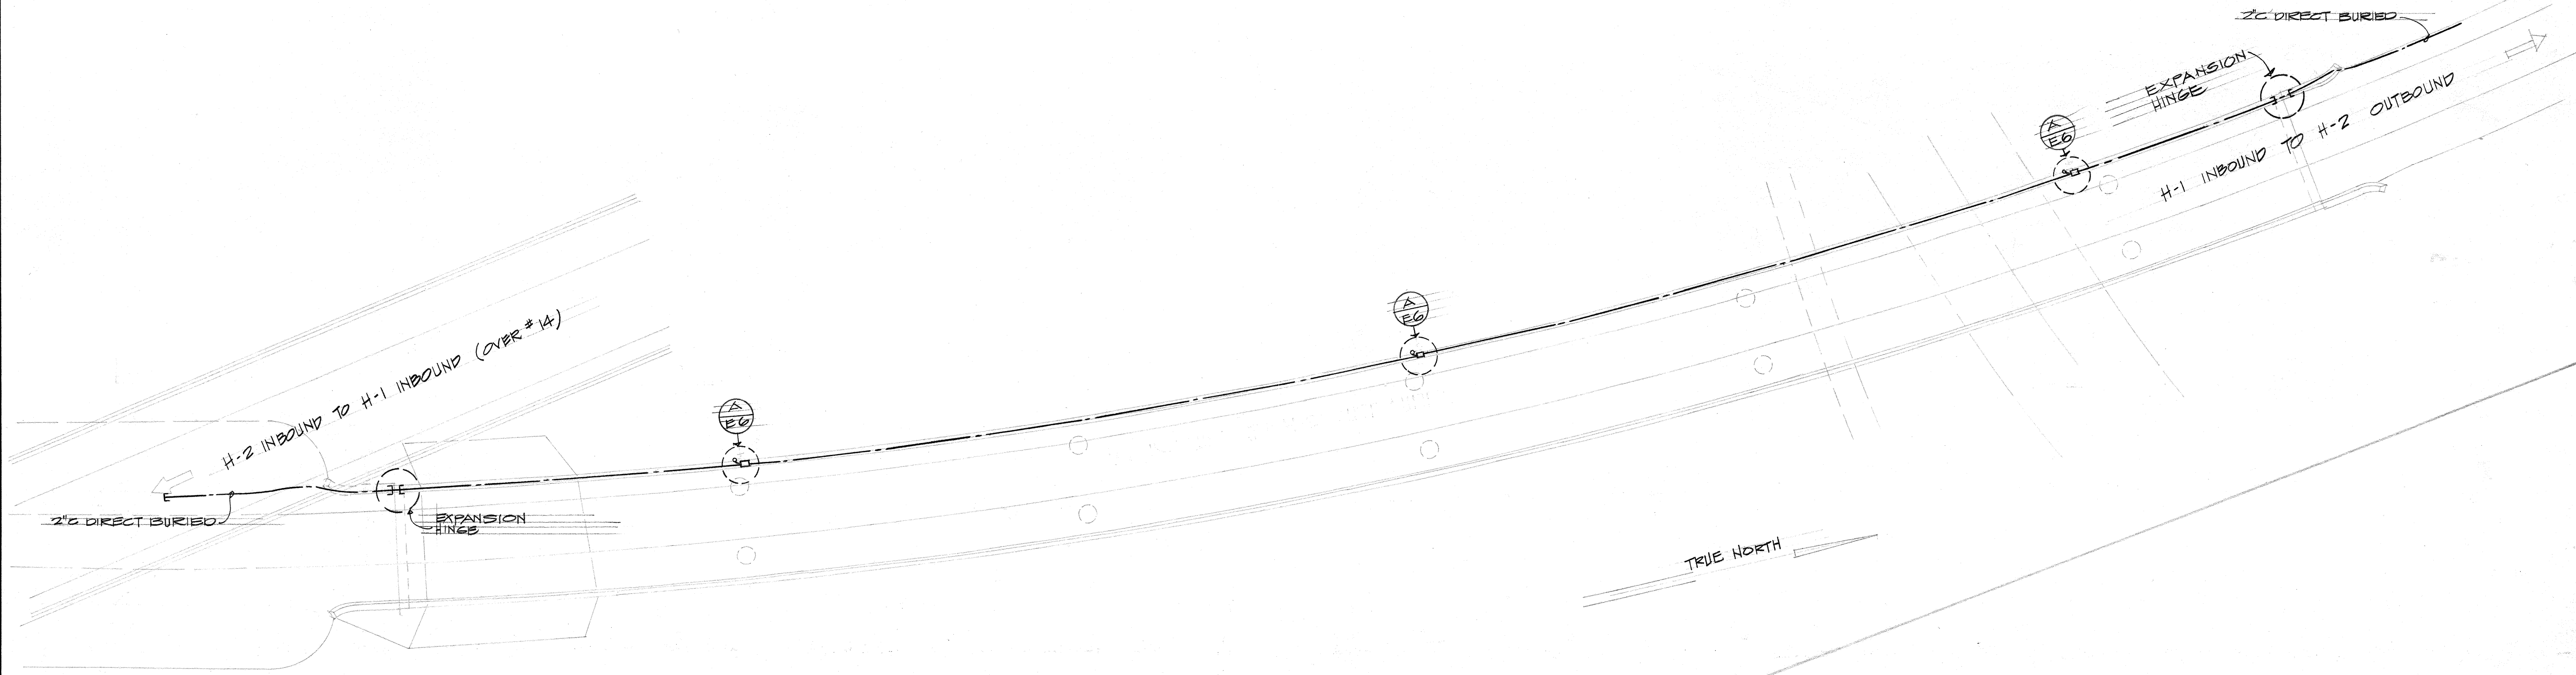

RACEWAY - STRUCTURE #14
SCALE: 1" = 20'-0"

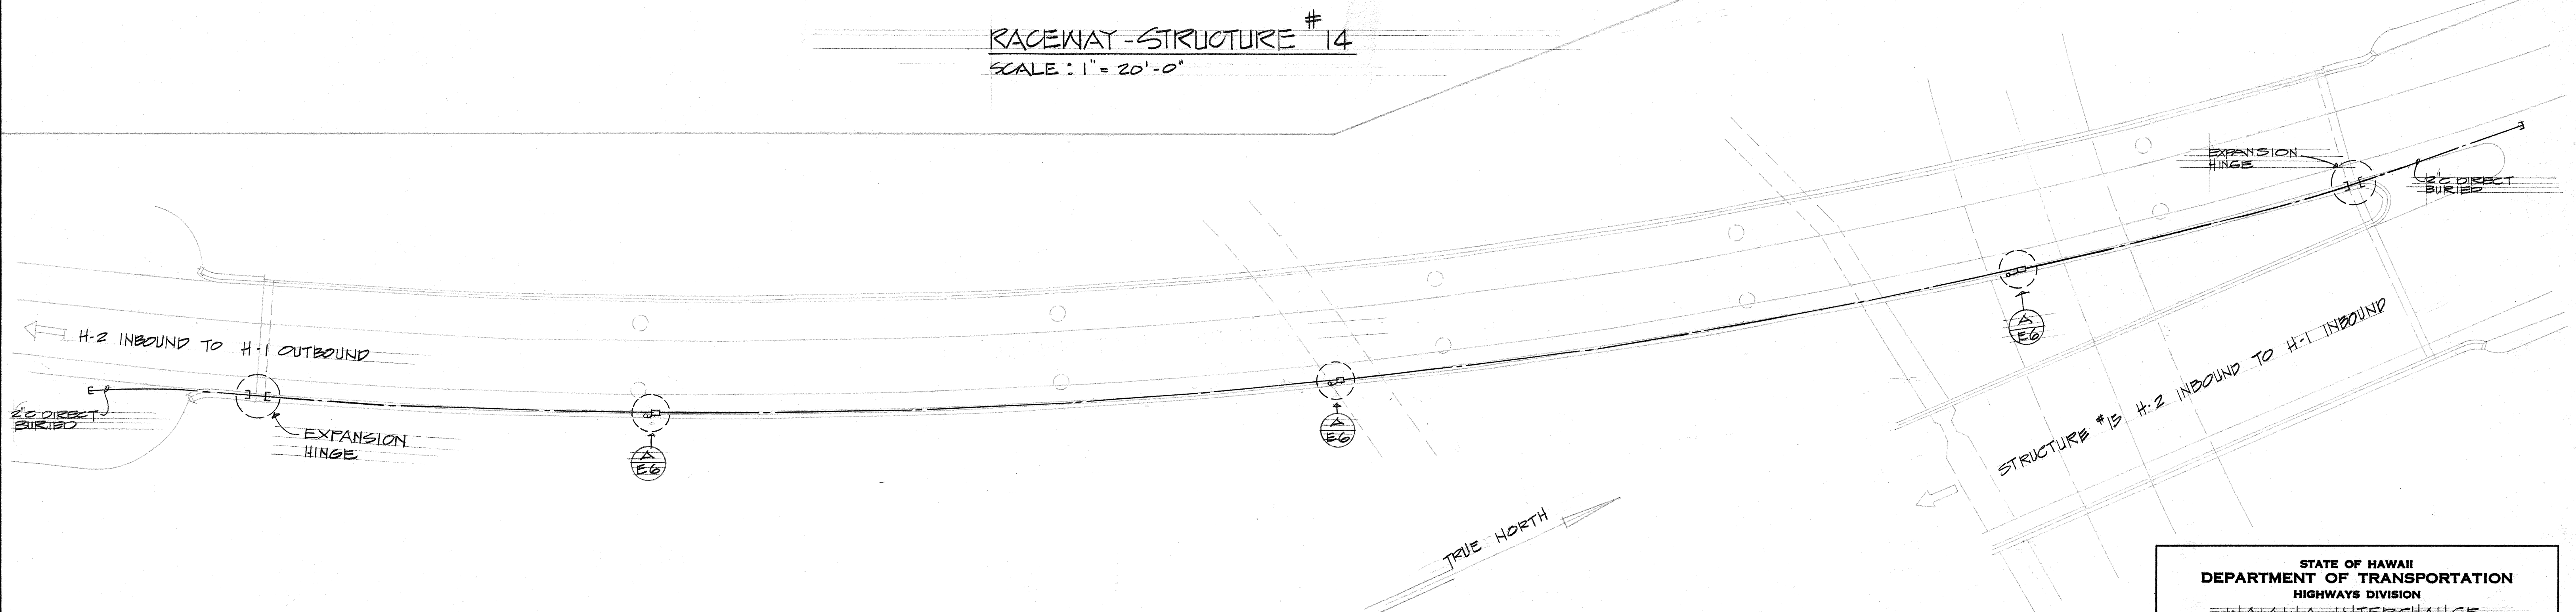

RACEWAY PLAN - STRUCTURE #16
SCALE: 1" = 20'-0"

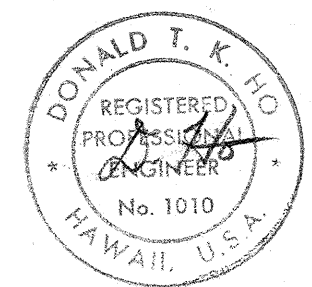


THIS WORK WAS PREPARED BY ME OR UNDER MY SUPERVISION.

STATE OF HAWAII
DEPARTMENT OF TRANSPORTATION
HIGHWAYS DIVISION
WAIKAWA INTERCHANGE


STRUCTURES No. 14 & 16
ELECTRICAL RACEWAY PLAN

F.A. I. Proj. No. T-H-1 (75) : 8
Scale: As Shown Date:

DATE	_____
SURVEY PLOTTED BY	_____
DRAWN BY	_____
DESIGNED BY	_____
QUANTITIES BY	_____
CHECKED BY	_____
ORIGINAL PLAN	_____
NOTE BOOK	_____
No.	_____

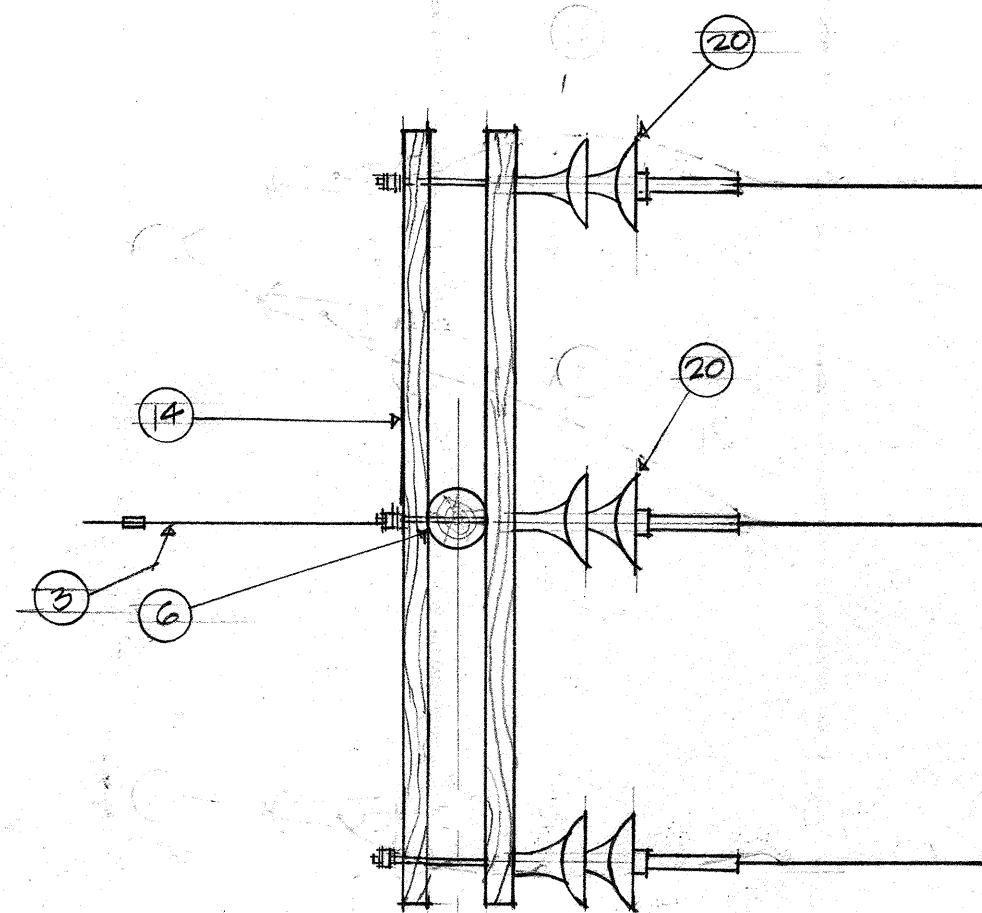


PLAN

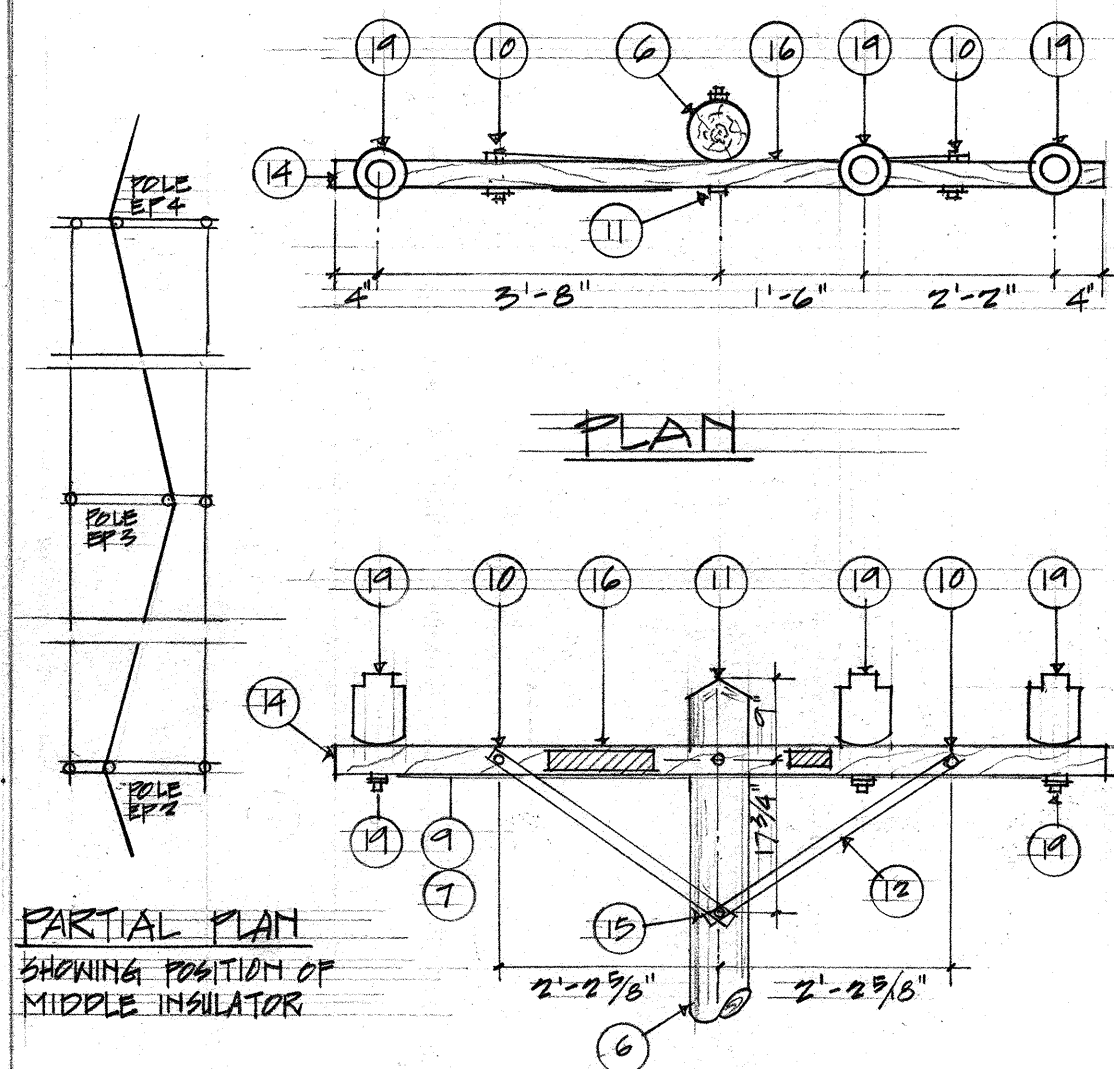


ELEVATION

P2 SINGLE ARM THRU CONDITION

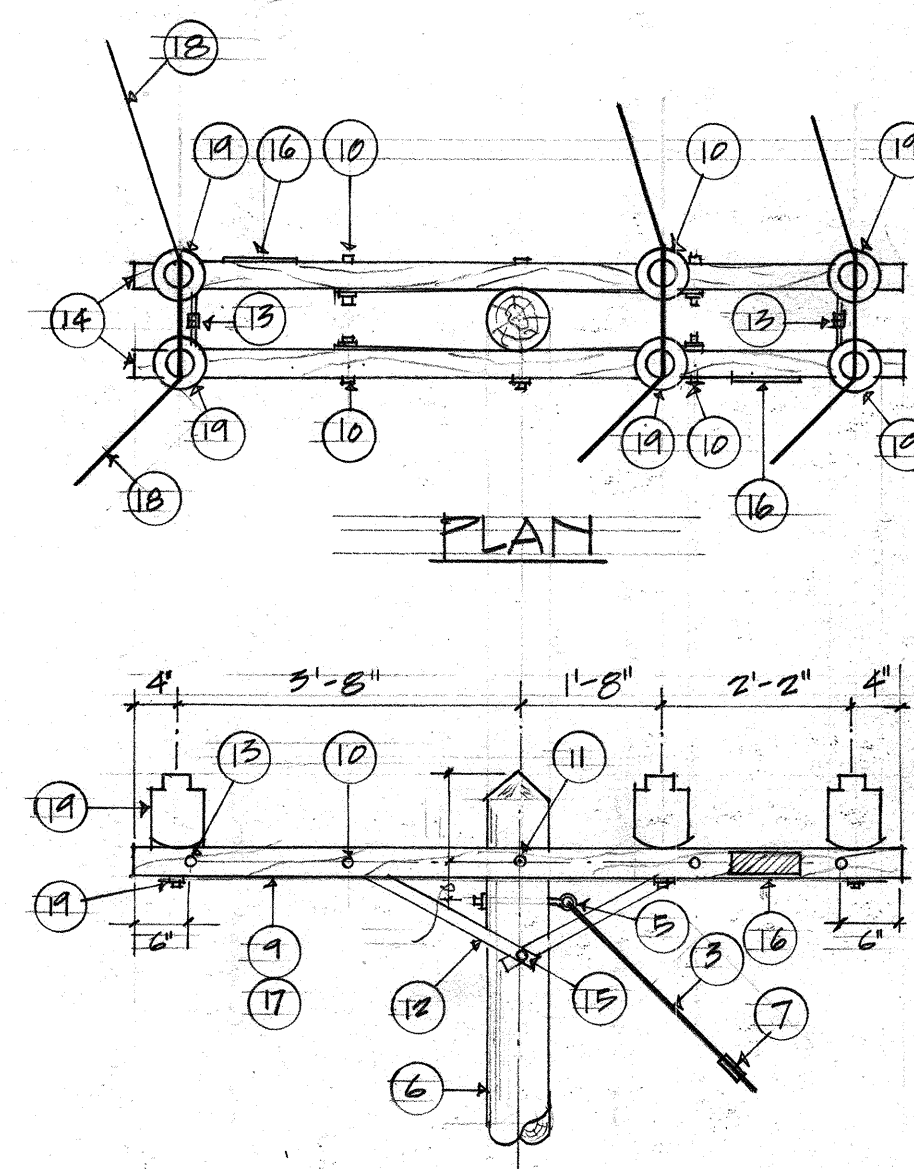


ELEVATION

P3 ANGLE CONSTRUCTION

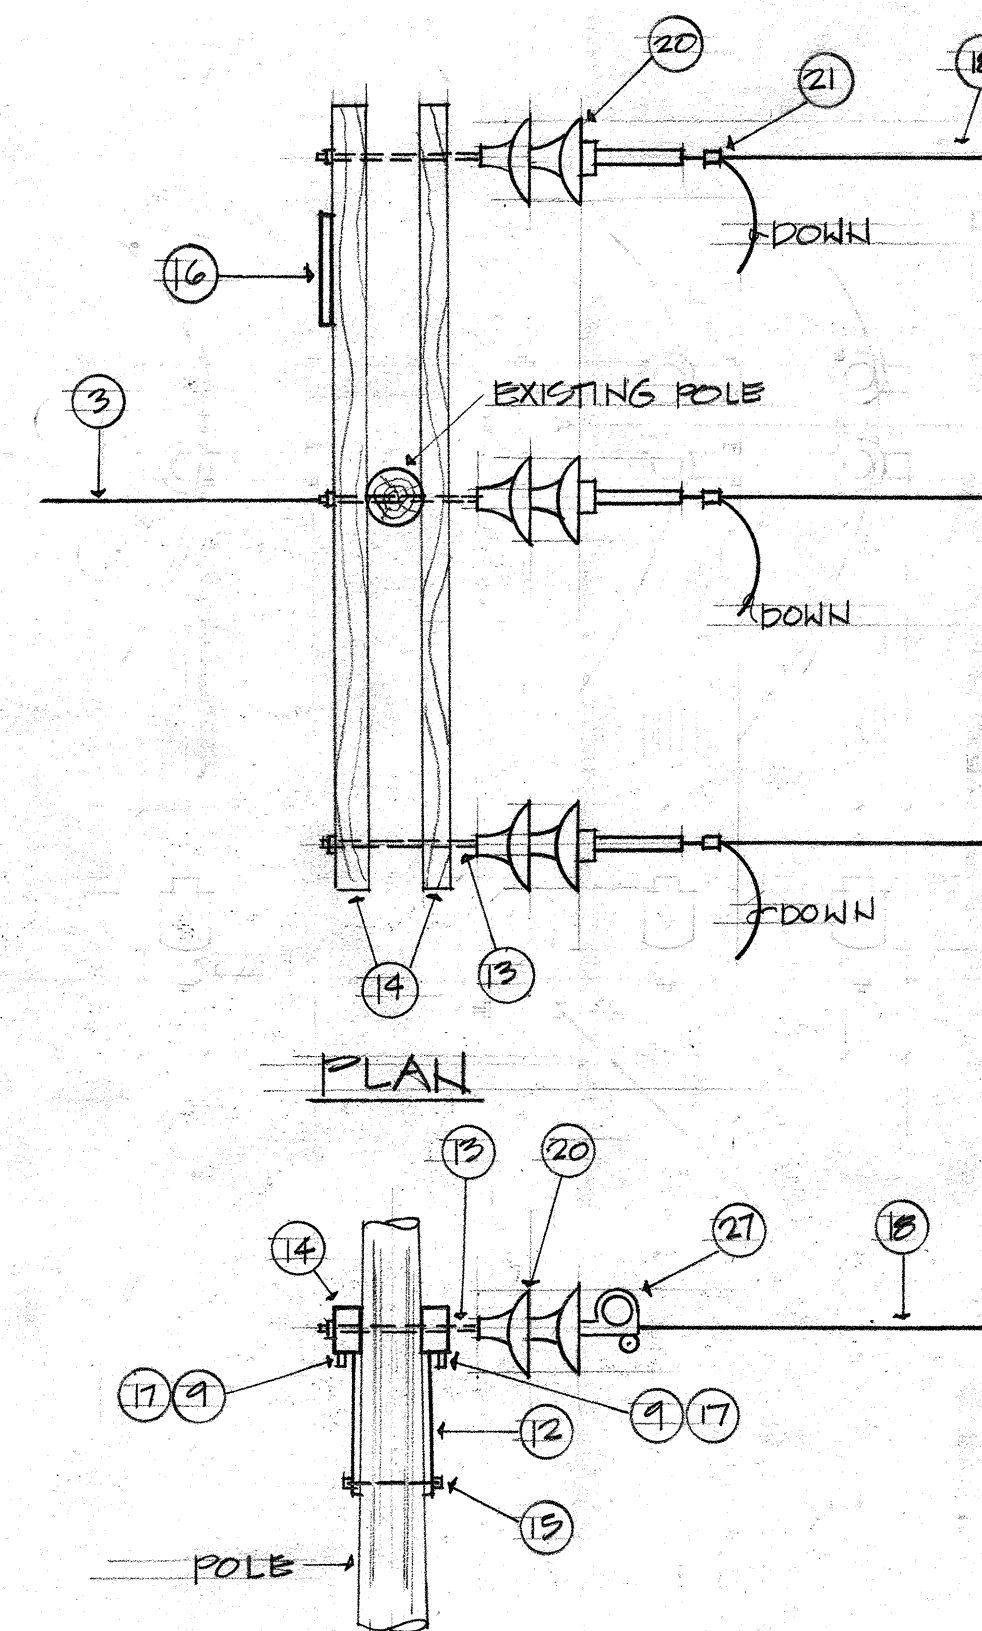


ELEVATION

P4 DEADEND CONDITION

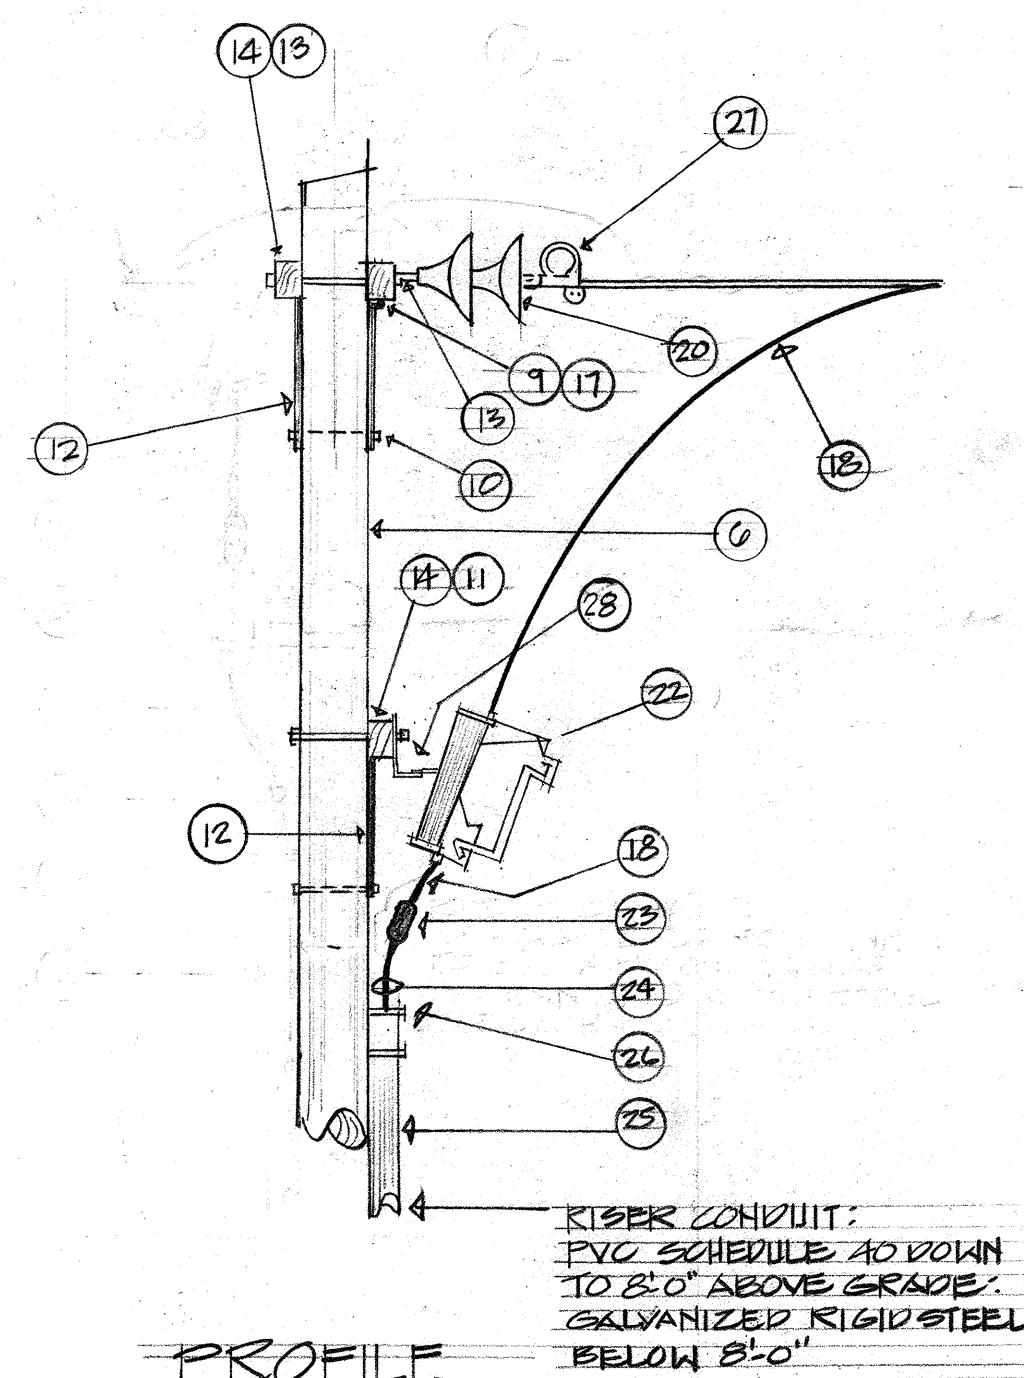


PROFILE

P1 DETAIL - RISER POLE FOR PRIMARY CABLE
NOT TO SCALE

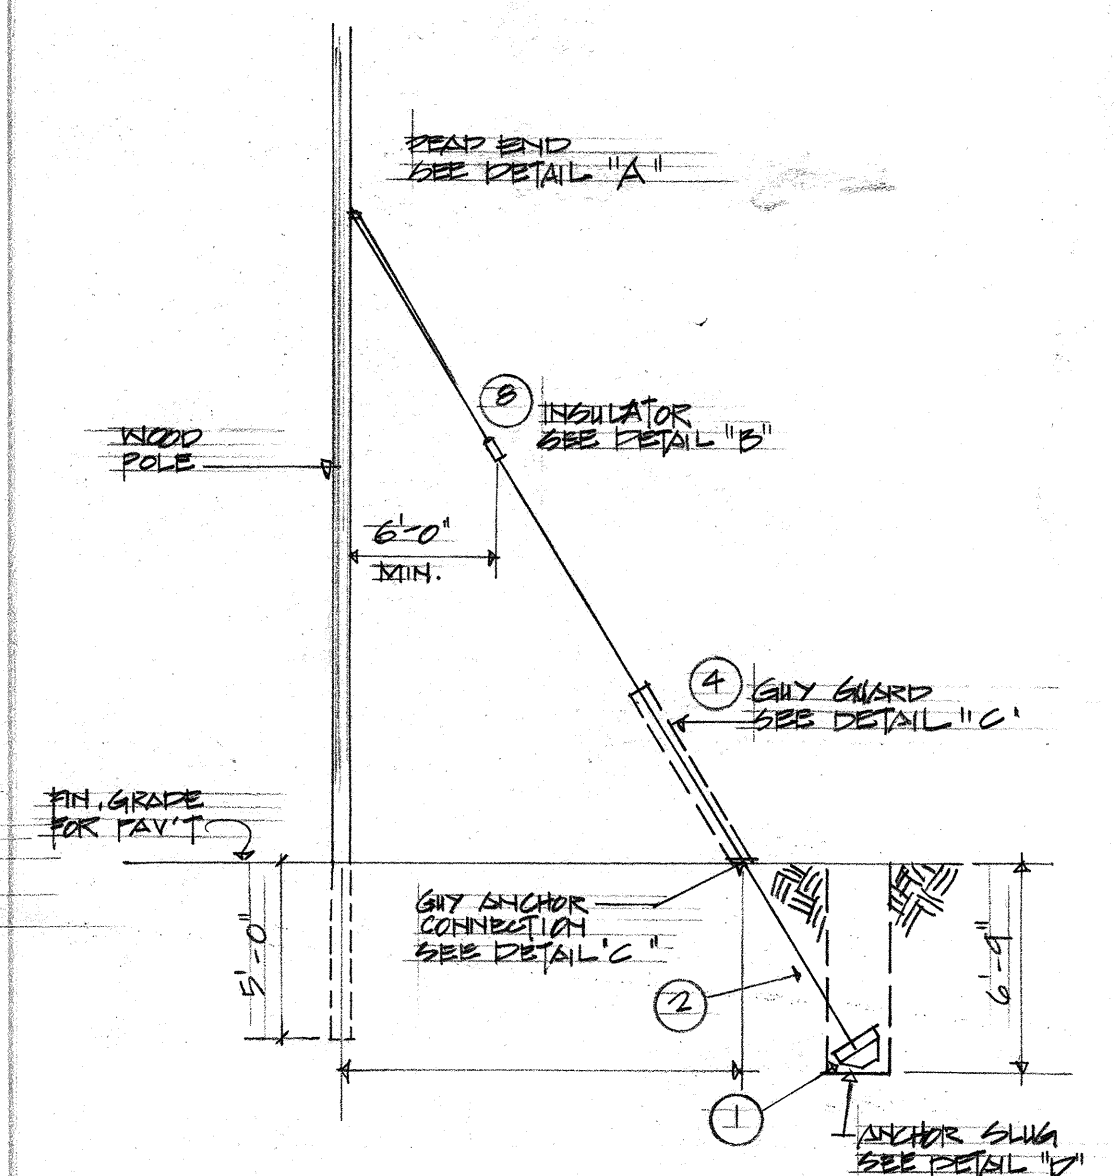


ELEVATION


ES ANCHOR AND GUYING DETAILS
NOT TO SCALE

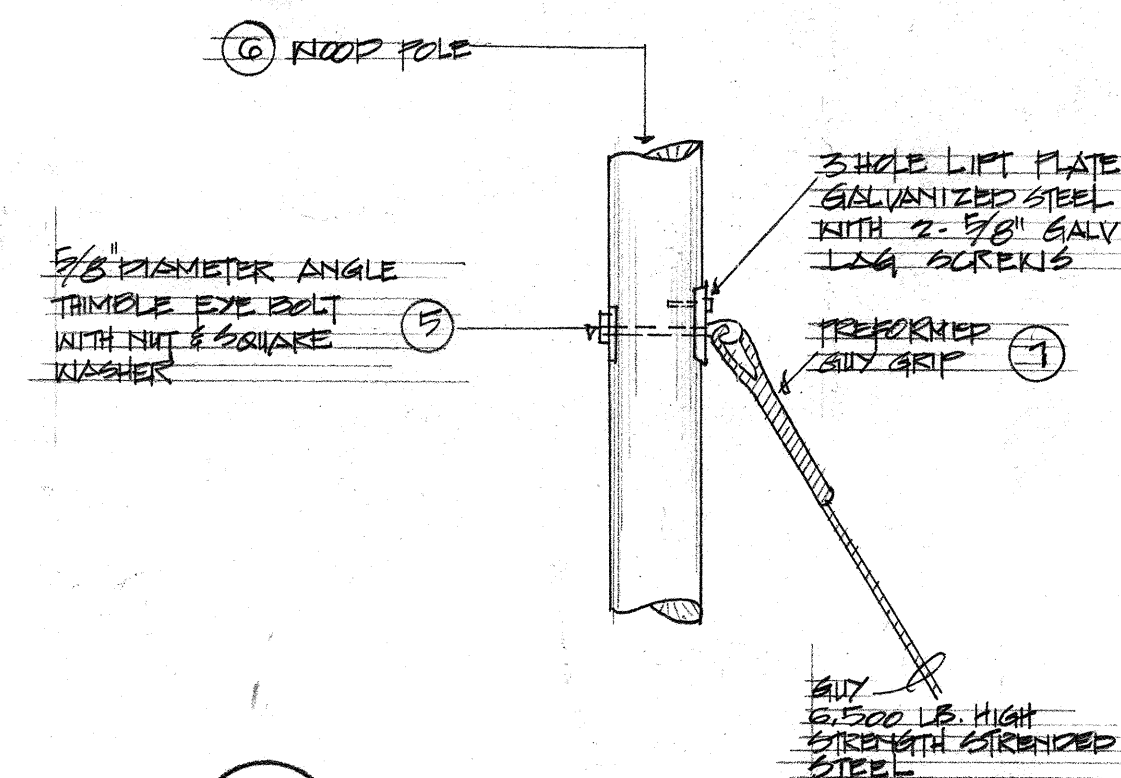


1-A ES DETAIL "A"

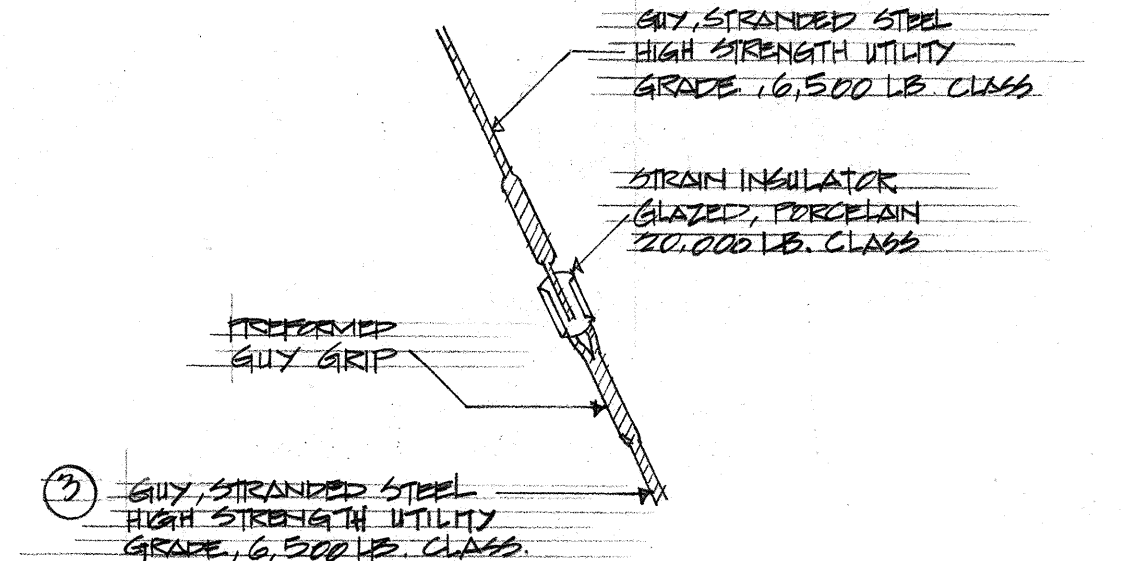

1-B ES DETAIL "B"

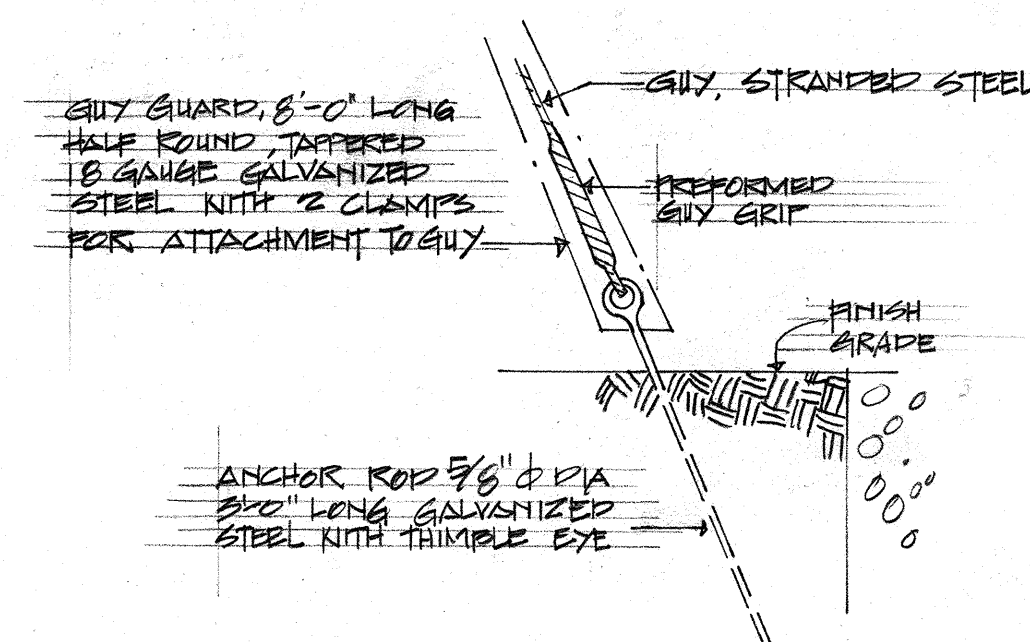


1-C ES DETAIL "C"

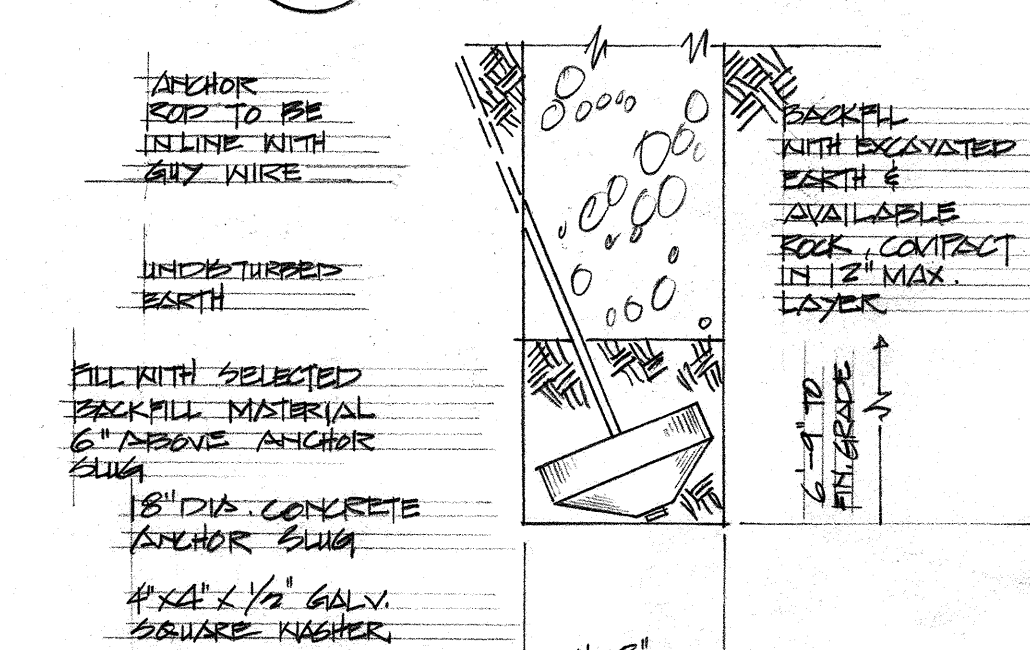

1-D ES DETAIL "D"

MATERIAL LIST - OVERHEAD SYSTEM

- POLE AND ANCHOR GROUP (SEE SPECIFICATION)
- ANCHOR SLUG, CONCRETE, 18" DIAMETER
 - ANCHOR ROD, 1" X 8'-0" TRIPLE EYE WITH WASHER & NUT
 - GUY STRAND, 3/8" DIAMETER
 - GUY GUARD, 8'-0" LONG, STEEL
 - GUY EYE BOLT, 3/8" DIAMETER
 - POLE, CREOSOTE, ASA CLASS 3
 - PREFORMED STRAND GRIPS
 - STRAIN INSULATOR, 20,000 LB. STRENGTH
 - BONDING WIRE, #6 SPEC & STAPLES
 - CROSSARM BRACE BOLT, MACHINE, 3/8" DIAMETER, WASHER & NUT
 - CROSSARM BOLT, 3/8" DIAMETER, WASHER & NUT
 - CROSSARM BRACE, 1/4" X 1/4" X 34"
 - DOUBLE ARMING BOLT, 3/8" DIAMETER, WASHER & NUT
 - CROSSARM 3/4" X 4 1/2" X 8'-0"
 - LAG SCREW, 1/2" DIAMETER
 - SIGN, HIGH VOLTAGE WITH FLATHEAD NAILS
 - WOOD MOLDING, 1/2" KIRING WITH 2-HOLE STRAP & NAILS
 - CONDUCTOR, PRIMARY, 12,000 VOLTS, NO.10 MHPEC
 - INSULATOR, 15 KV, POST TYPE WITH STEEL PINS
 - INSULATOR, 15 KV, CLEVELAND W/ 3/8" MOUNTING BOLT, WASHER & NUT
 - LINE CONNECTOR
 - FUSER CUTOUT, 15 KV, 100 A
 - STRESS RELIEF ZONE, PREMOULDED, 15KV
 - PRIMARY CABLE, 3/C #350MCM, PEI, 15KV
 - RISER CONDUIT, 4" PVC SCHEDULE 40
 - SEALING COMPOUND
 - UNIVERSAL STRAIN CLAMP
 - CUTOUT MOUNTING BRACKET

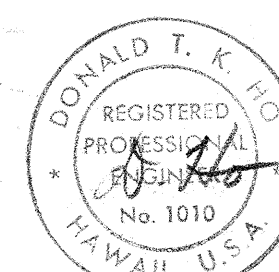

THIS WORK WAS PREPARED BY
ME OR UNDER MY SUPERVISION.






STATE OF HAWAII
DEPARTMENT OF TRANSPORTATION
HIGHWAYS DIVISION
NAIWA INTERCHANGE

POLE FRAMING DETAILS





F.A.I. Proj. No. I-HI-1(15)-8
Scale: As shown Date:

SHEET No. E5 OF 17 SHEETS

FED. ROAD DIST. NO.	STATE	FED. AID PROJ. NO.	FISCAL YEAR	SHEET NO.	TOTAL SHEETS
HAWAII	HAW.	EH-1(15)B	1969	96	181

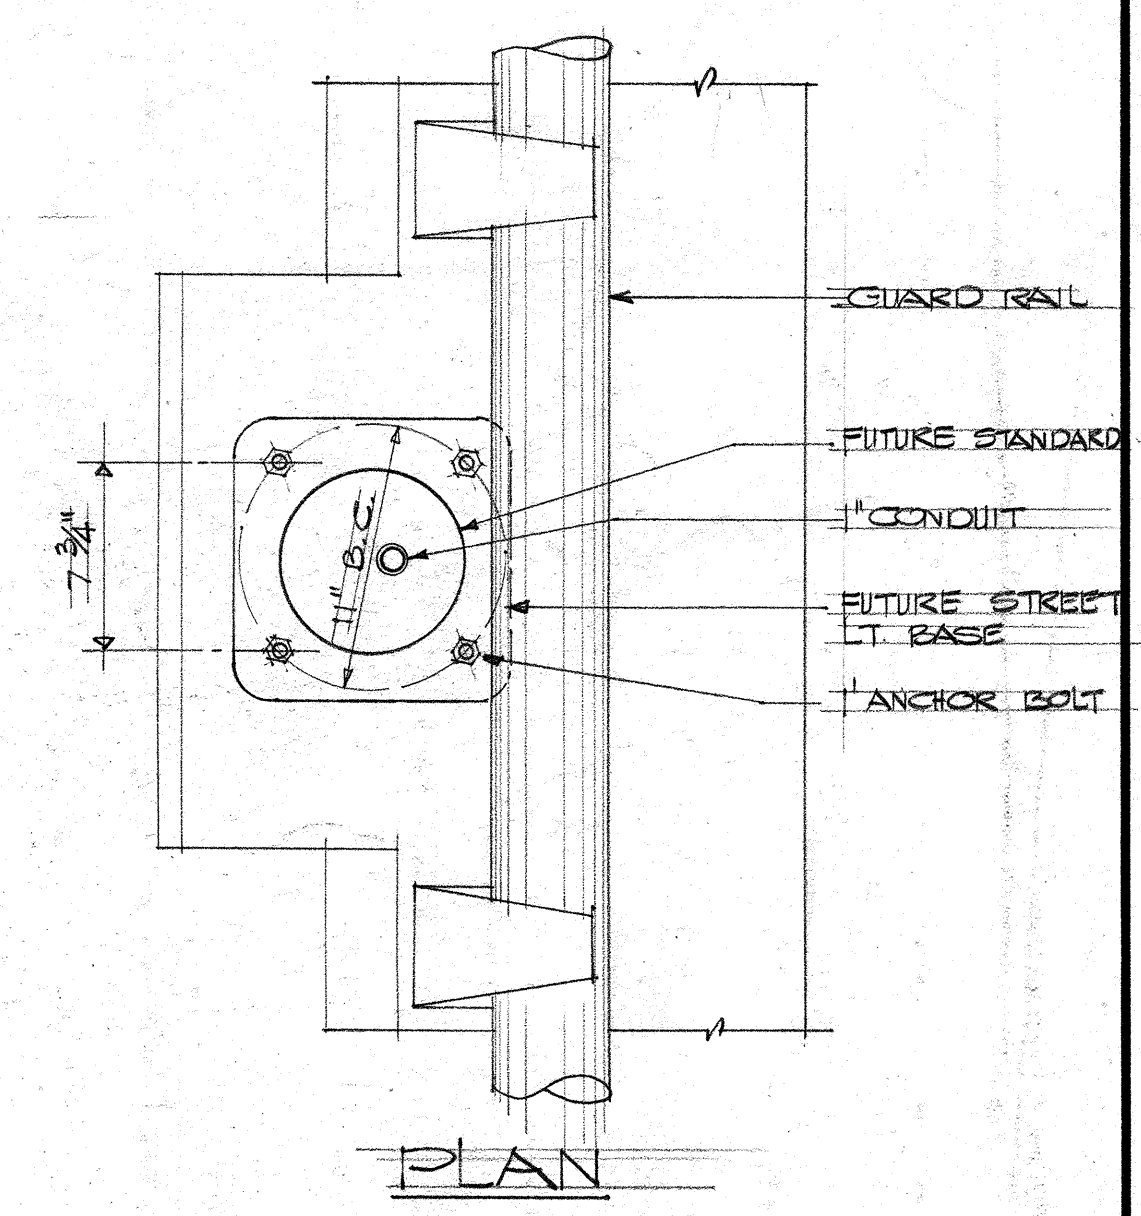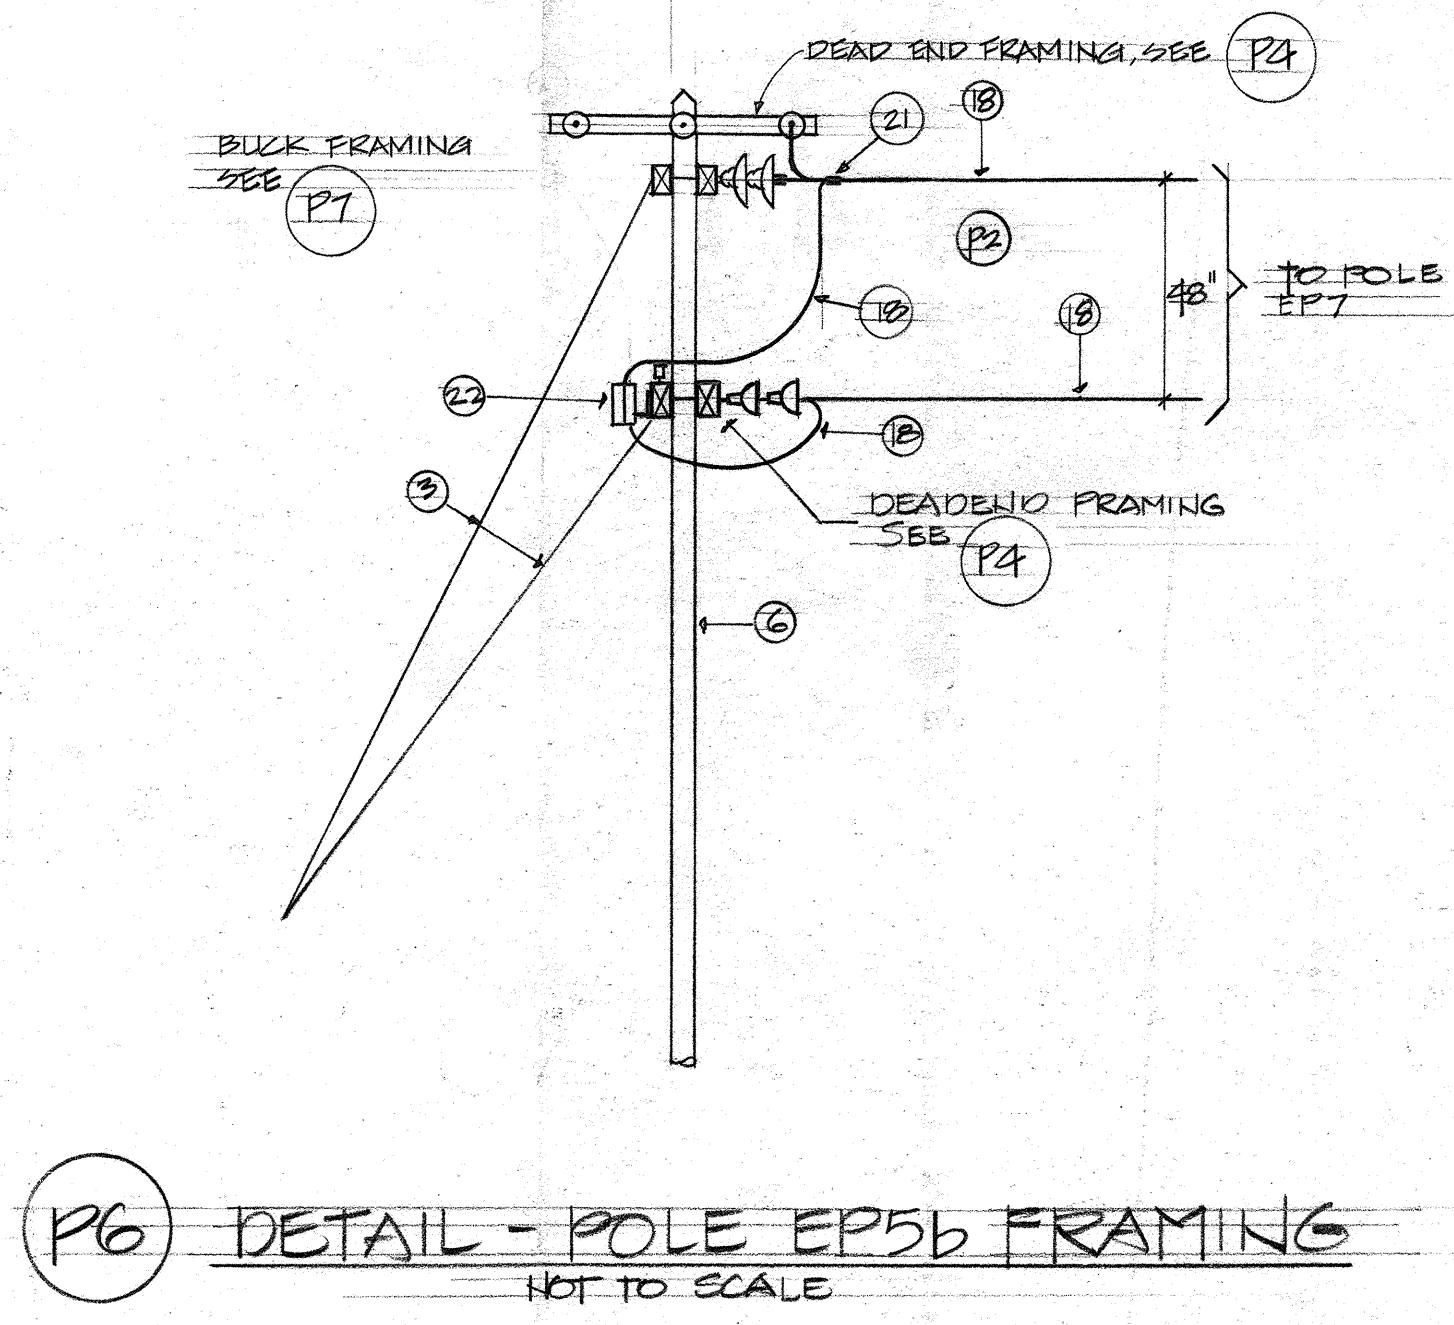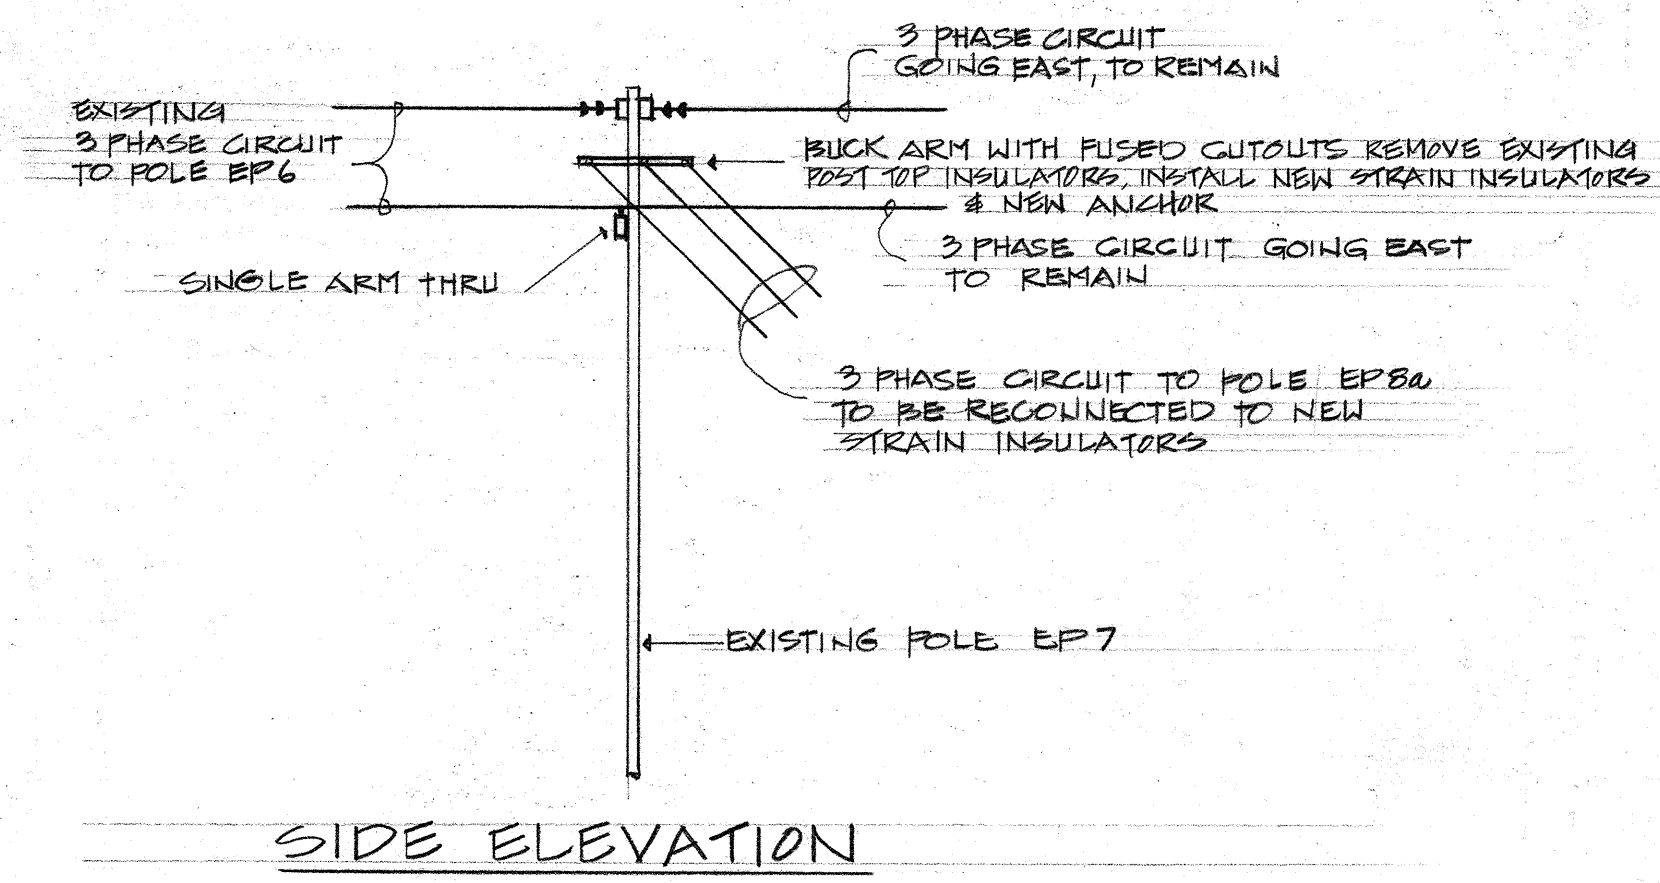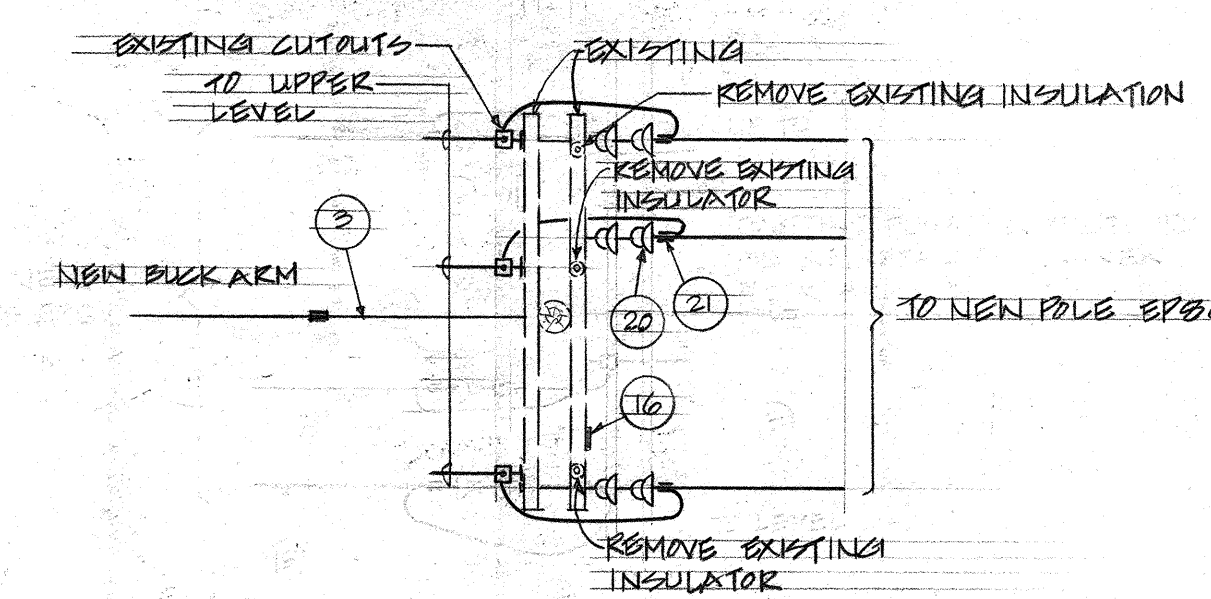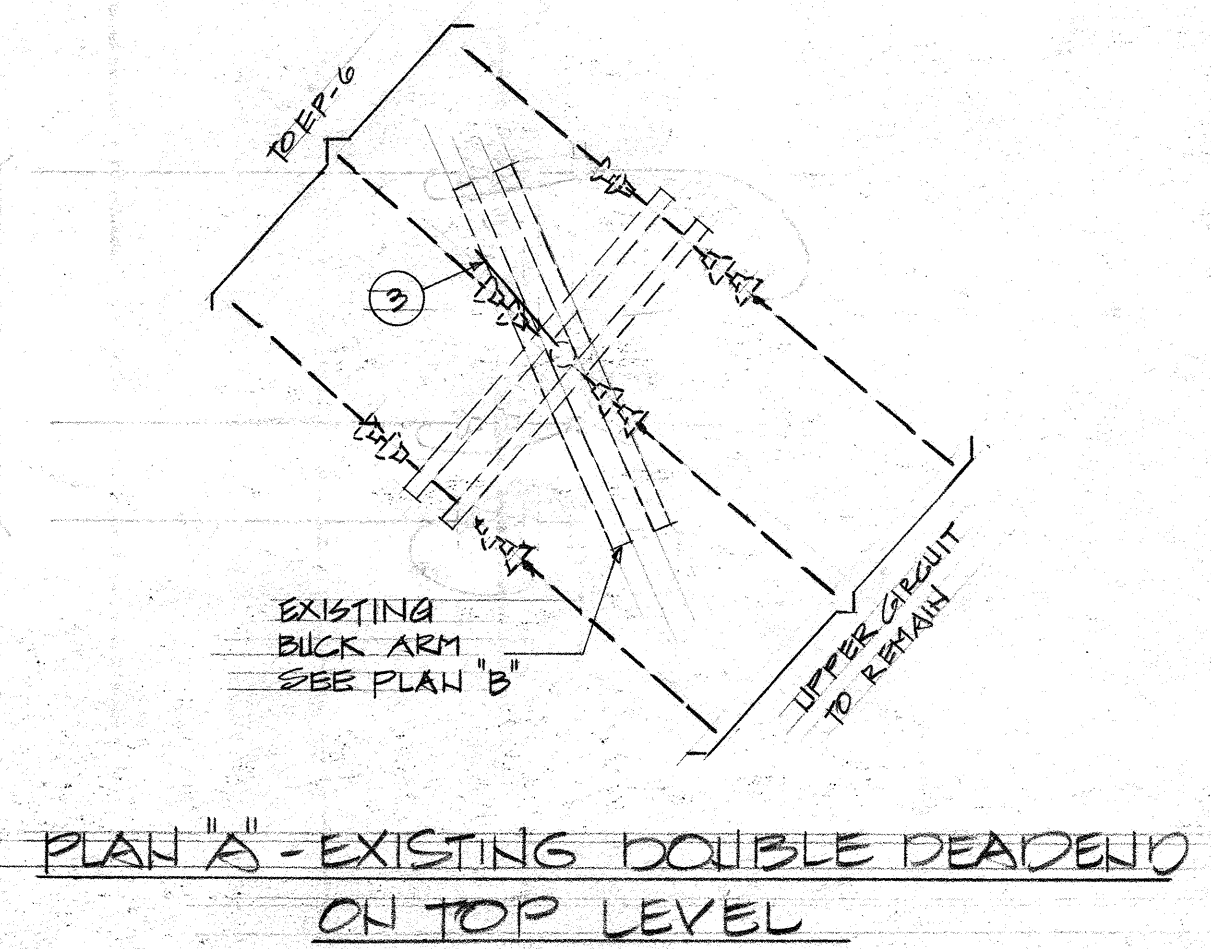

P5 DETAIL - FRAMING POLE EP 7
NOT TO SCALE

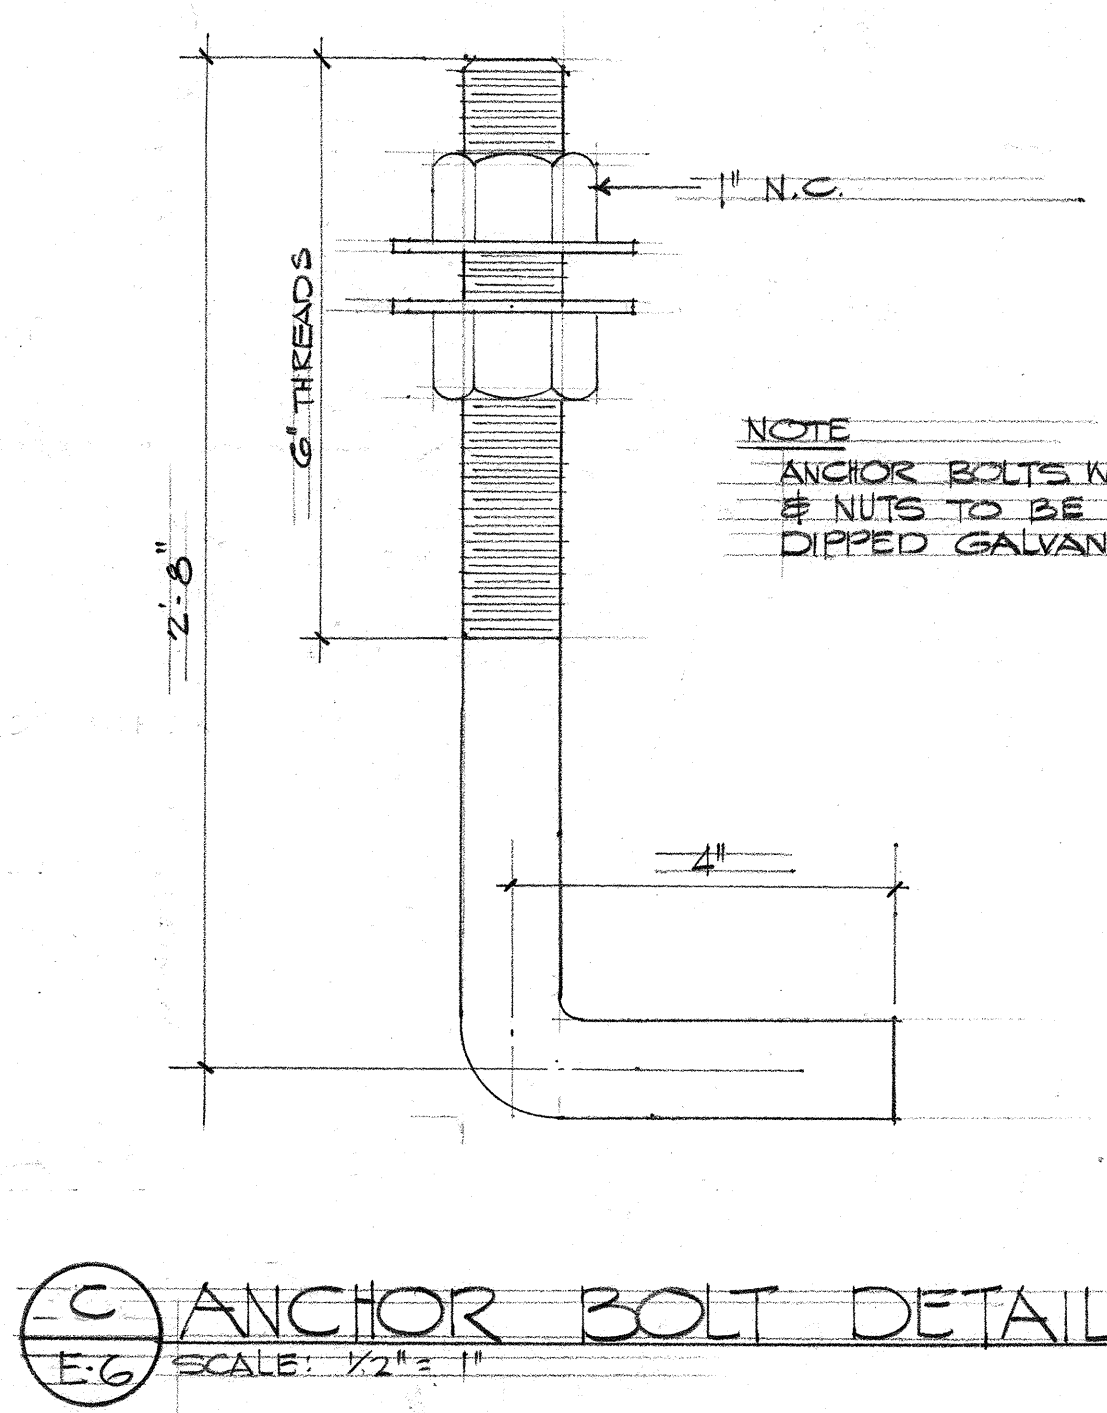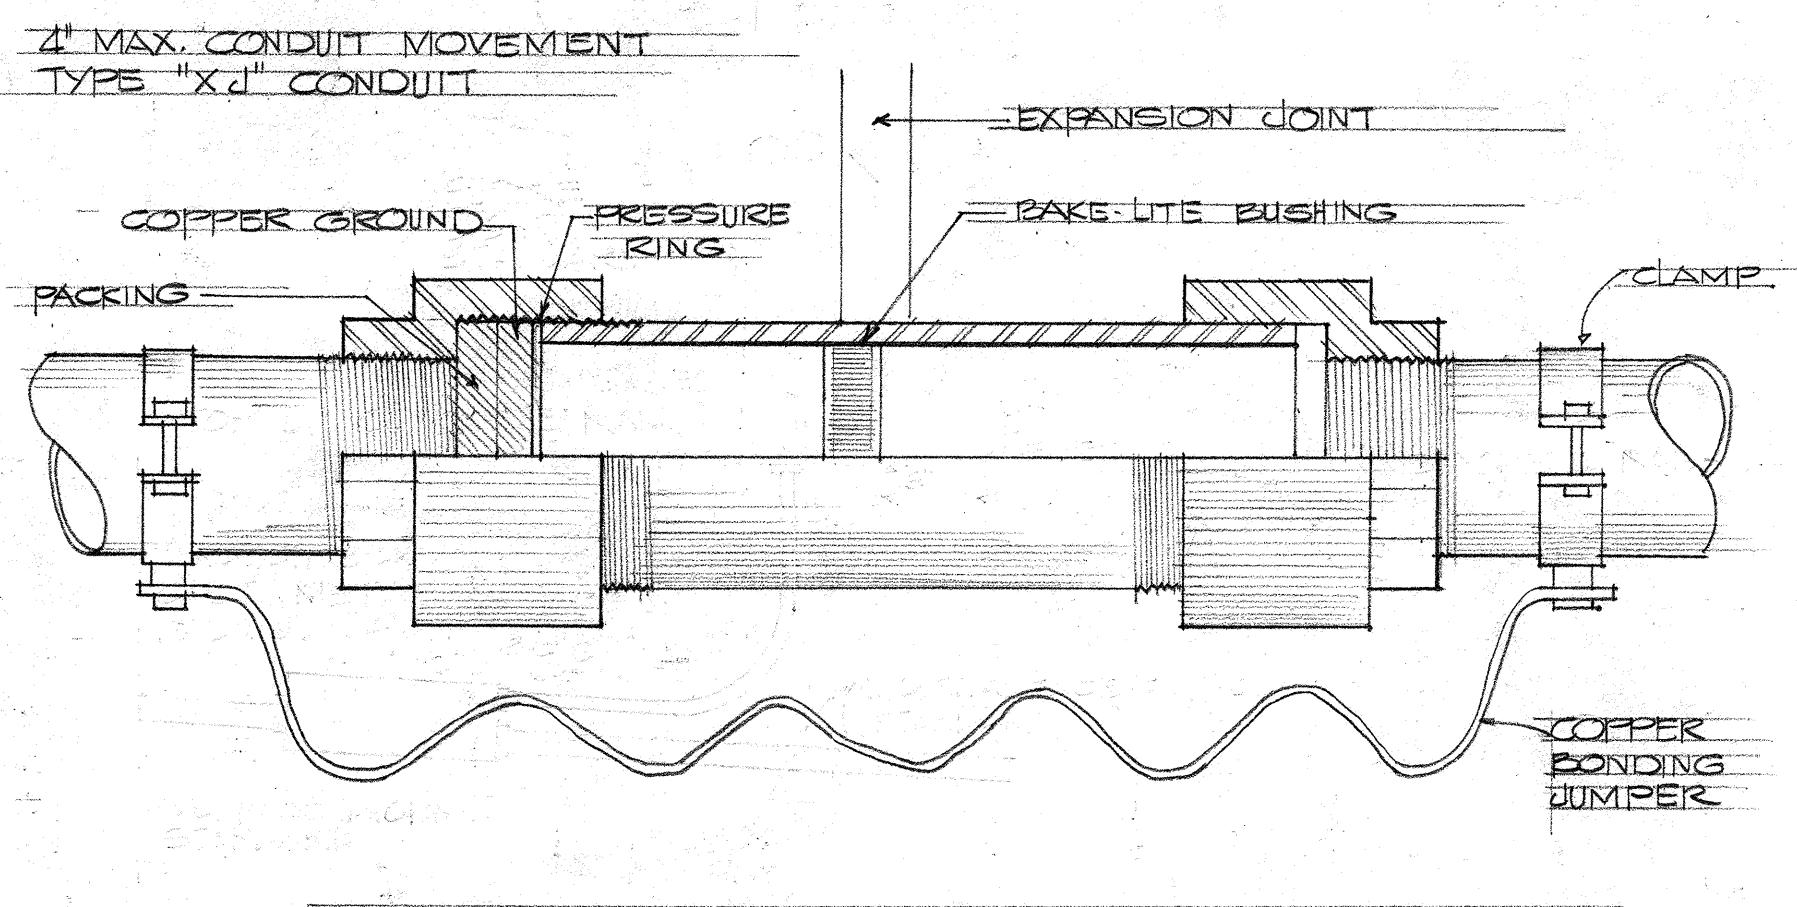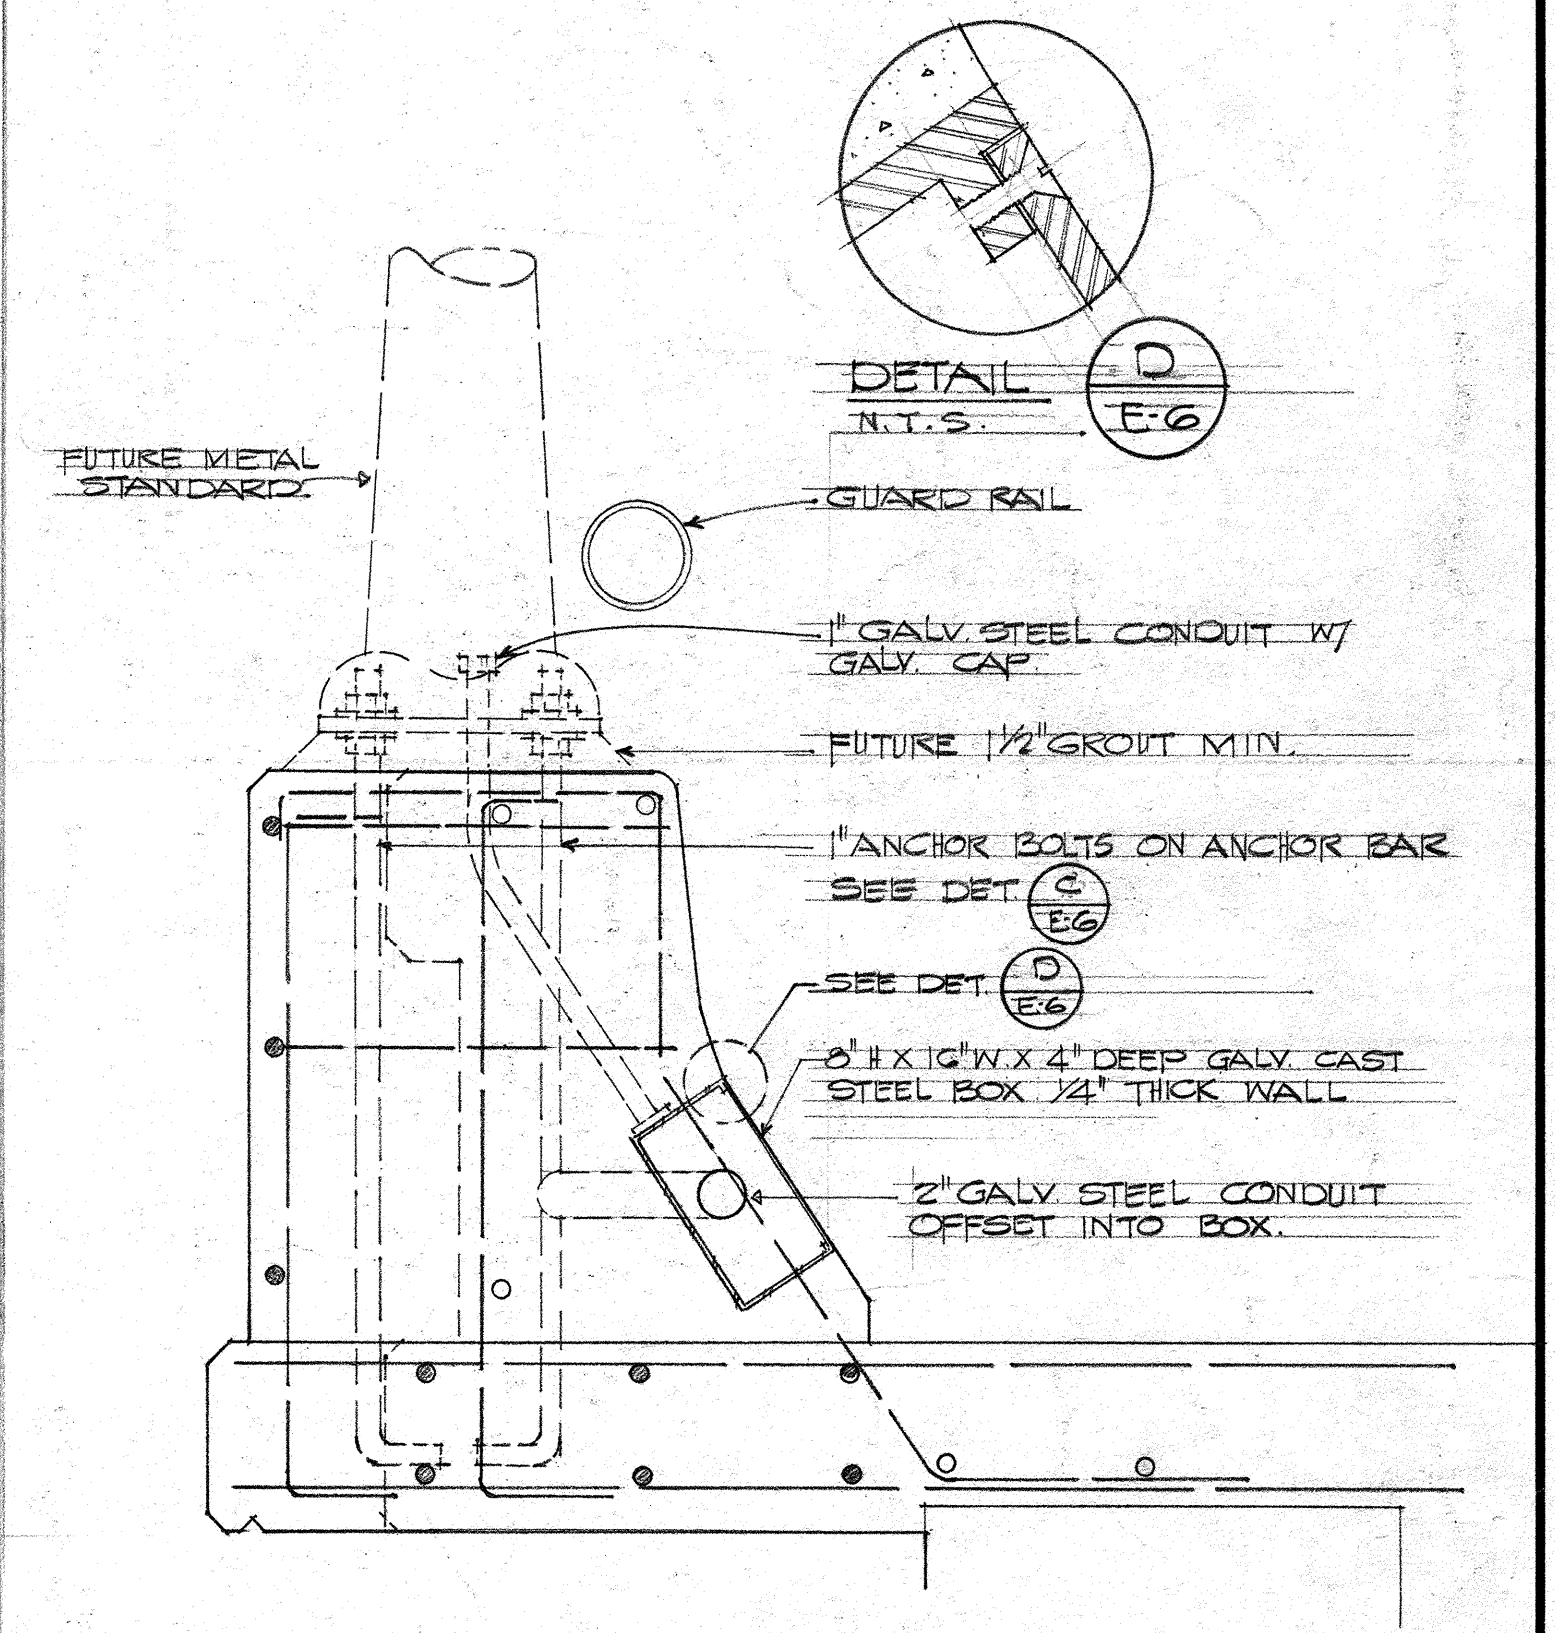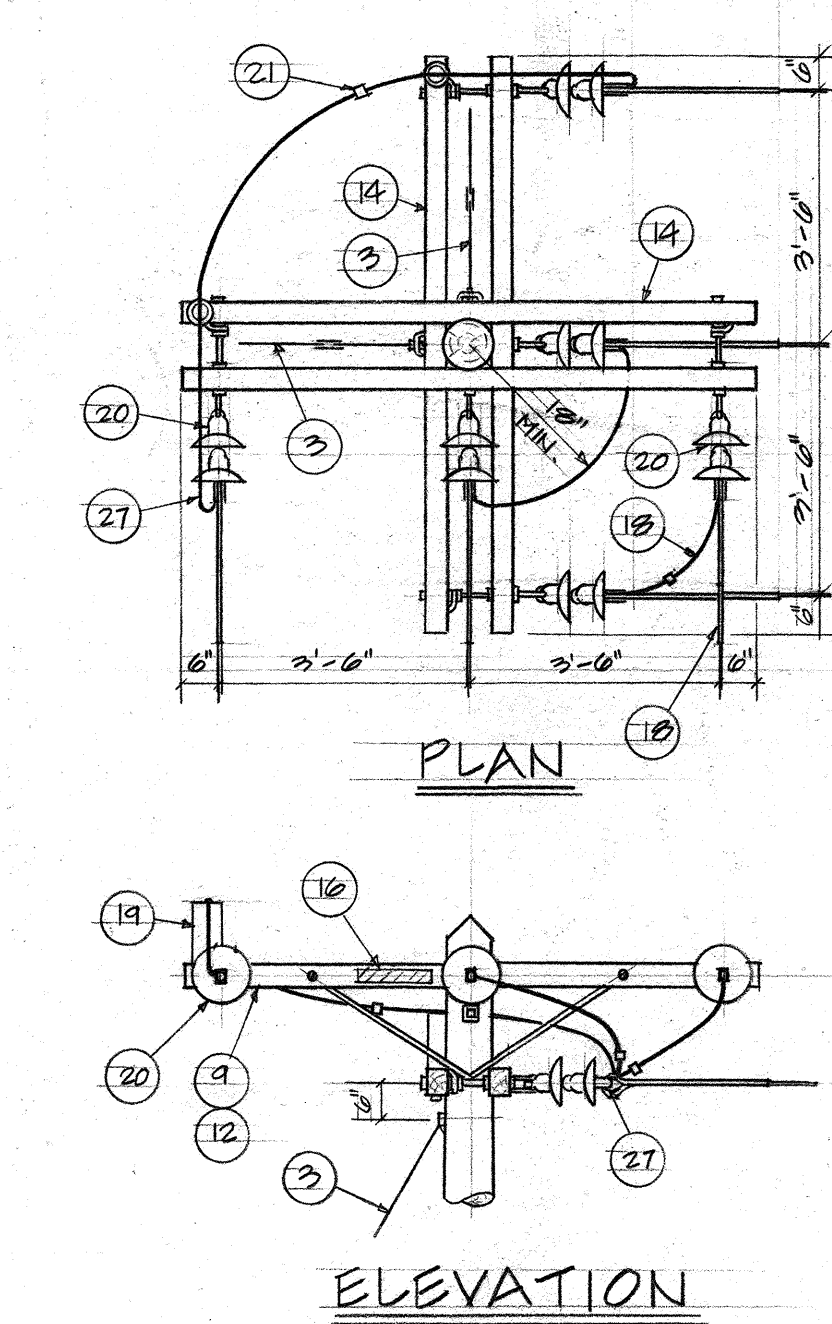

SECTION
A TYPICAL LIGHT BASE DETAIL
E-G SCALE: 1/2" = 1'-0"

STATE OF HAWAII
DEPARTMENT OF TRANSPORTATION
HIGHWAYS DIVISION
WAIKAWA INTERCHANGE

POLE FRAMING DETAILS &
HIGHWAY LIGHTING DETAILS

F.A. I Proj. No. I-H-1 (75):B

Scales: AS SHOWN Date:

SHEET No. E-G OF 17 SHEETS

THIS WORK WAS PREPARED BY
ME OR UNDER MY SUPERVISION.

DONALD T. K. HO
REGISTERED PROFESSIONAL
ENGINEER
No. 1010
HAWAII, U.S.A.

DATE	_____
SURVEY PLOTTED BY	_____
DRAWN BY	_____
DESIGNED BY	_____
QUANTITIES BY	_____
CHECKED BY	_____
ORIGINAL PLAN	_____
NOTE BOOK	_____
No.	_____

GENERAL NOTES:


1. CONDUITS FOR HTCO SHALL BE FURNISHED BY HTCO, INSTALLED BY CONTRACTOR.
2. CONDUITS FOR HECO. SHALL BE FURNISHED BY HECO, INSTALLED BY CONTRACTOR
3. CONDUITS FOR CAHU SUGAR (QS.CO) SHALL BE FURNISHED & INSTALLED BY CONTRACTOR.
4. GROUTED RUBBLE PAVING SHALL BE ACCORDING TO SPECIFICATION
5. CONCRETE FOR DUCTLINE SHALL BE 2500 PSI STRENGTH IN 28 DAYS.
6. SEE SPECIFICATION OF SELECT BACKFILL OVER DIRECT BURIED CABLES AND DIRECT BURIED CONDUITS, AND BACKFILL OVER CONCRETE ENCASED DUCTS AND SELECT BACKFILL.




STATE OF HAWAII
DEPARTMENT OF TRANSPORTATION
HIGHWAYS DIVISION
WAI'ANA INTERCHANGE
DUCT SECTIONS & ONE LINE
DIAGRAM, 11 KV RECONNECTION
F.A.I Proj No. I-HI-1 (75) : 8
Scale: AS SHOWN
SHEET No. E-7 OF 17 SHEETS

NOTES:


- 4" GALVANIZED STEEL PIPES SHALL BE PLACED ACROSS ROADWAY (ROAD 'A') AND AT SUCH DEPTHS FROM FINISHED GRADES AS INDICATES.
- BOTH ENDS OF EACH LENGTH OF PIPE SHALL BE REAMED BEFORE JOINING TO INSURE NO BURRS OR SHARP EDGES EXIST.
- WHERE IT IS NECESSARY TO CUT AND JOIN PIPE EITHER THREADED OR WELDED CONNECTION MAY BE EMPLOYED.
- WHERE PIPE IS JOINED BY WELDING, A 4-6 INCH SHUG FITTING LENGTH OF STEEL SLEEVEING SHALL BE CENTERED OVER THE BUTT ENDS. THE BUTT ENDS OF THE PIPE SHALL BE TRUE AND PLACED FLUSH TOGETHER. THE WELD SHALL BE MADE AT THE JUNCTION OF THE SLEEVE END AND PIPE. IN NO CASE SHALL AN ATTEMPT BE MADE TO WELD THE BUTT ENDS OF THE PIPE TOGETHER.
- WELDED JOINTS AND OTHER AREAS ON THE PIPE WHERE GALVANIZING HAS BEEN DAMAGED SHALL BE COVERED WITH TWO HALF LAP LAYERS OF TAPE COAT OR EQUAL.
- CHANGE IN GRADE SHALL BE GRADUAL AND BENDS SHALL HAVE A RADIUS OF NOT LESS THAN 4 FEET, PREFERABLY MORE.
- SPLICE PITS WILL BE DIG AT SPLICE LOCATIONS 1 AND 2. THE MINIMUM SIZE OF SPLICE PIT SHALL BE 7'-0" IN LENGTH, 6'-0" IN WIDTH AND TO A DEPTH 1'-0" BELOW EXISTING TELEPHONE CABLE. WHERE NECESSARY, ADEQUATE SHORING SHALL BE PROVIDED TO INSURE SAFE WORKING CONDITIONS FOR THE SPLICING CREWS.
- BACKFILLING OF THE PIPE SECTIONS SHALL BE AT THE DIRECTION OF H.T.CO. AND STATE INSPECTORS. BACKFILL IN GENERAL SHALL CONSIST OF THE EARTH REMOVED FROM TRENCH. IT SHALL NOT INCLUDE LOGS, STUMPS, TIN CANS, OR OTHER DEBRIS. WHERE ROCK IS REMOVED FROM THE TRENCH, SPECIAL CARE SHALL BE EXERCISED IN BACKFILLING.
- THE TRENCH AND SPLICE PIT SHALL BE THOROUGHLY COMPACTED FROM BOTTOM TO TOP AND SHALL MEET THE STANDARD SPECIFICATIONS OF THE STATE OF HAWAII, HIGHWAY DIVISION.
- TAMPING OF BACKFILL MATERIALS SHALL BE DONE IN SUCH MANNER THAT WILL NOT CAUSE ANY DAMAGE TO TELEPHONE CABLE AND FOREIGN UTILITIES.
- CAP AND MARK BOTH ENDS OF VACANT 4" GGP CROSSING ROAD 'A'.
- IF NECESSARY CONTRACTOR WILL BE RESPONSIBLE FOR SUBMITTING H.T.CO. LAND LINE CABLE PERKING COMPLETION OF PERMANENT REROUTE. CONTRACTOR TO FURNISH AND PLACE ECHERDILE 40 PVC SPLIT DUCT AROUND EXPOSED PORTION OF CABLE TO AVOID ANY POSSIBLE DAMAGE. THIS WORK WHEN REQUIRED SHALL BE DONE AT CONTRACTORS EXPENSE AND AT NO ADDITIONAL COMPENSATION.

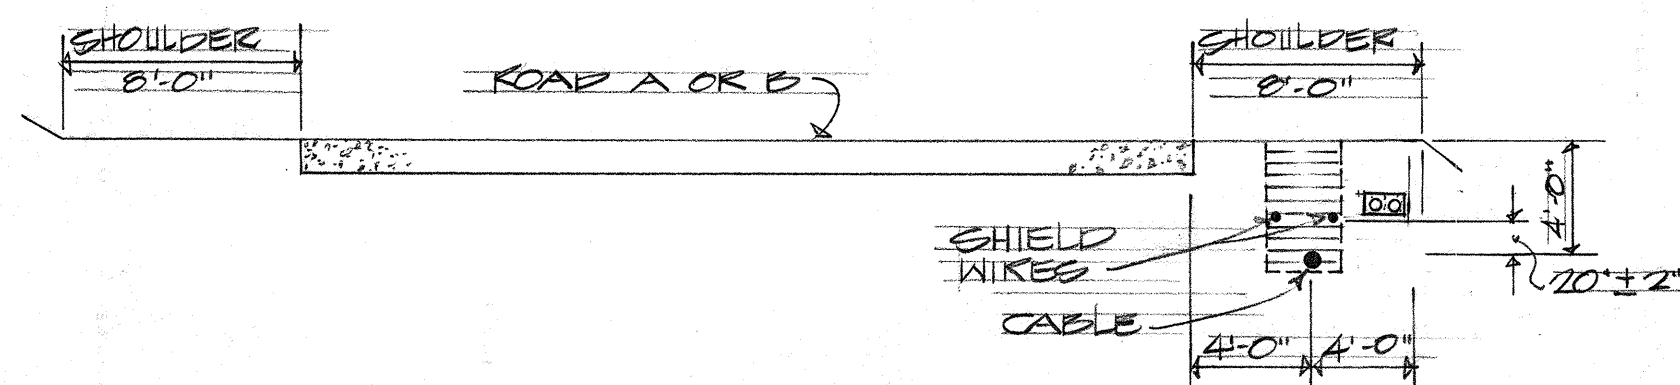


A
E-8
TYPICAL LOCATION OF TELEPHONE TP CABLE TRENCH OR CONDUITS
NOT TO SCALE

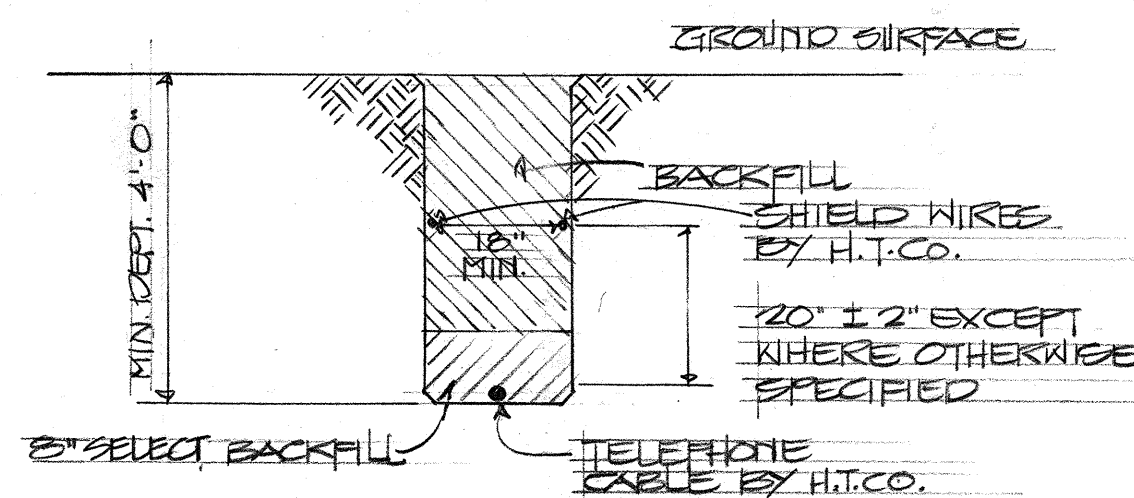


B
E-8
TYPICAL SECTION THROUGH NORMAL TRENCH
NOT TO SCALE

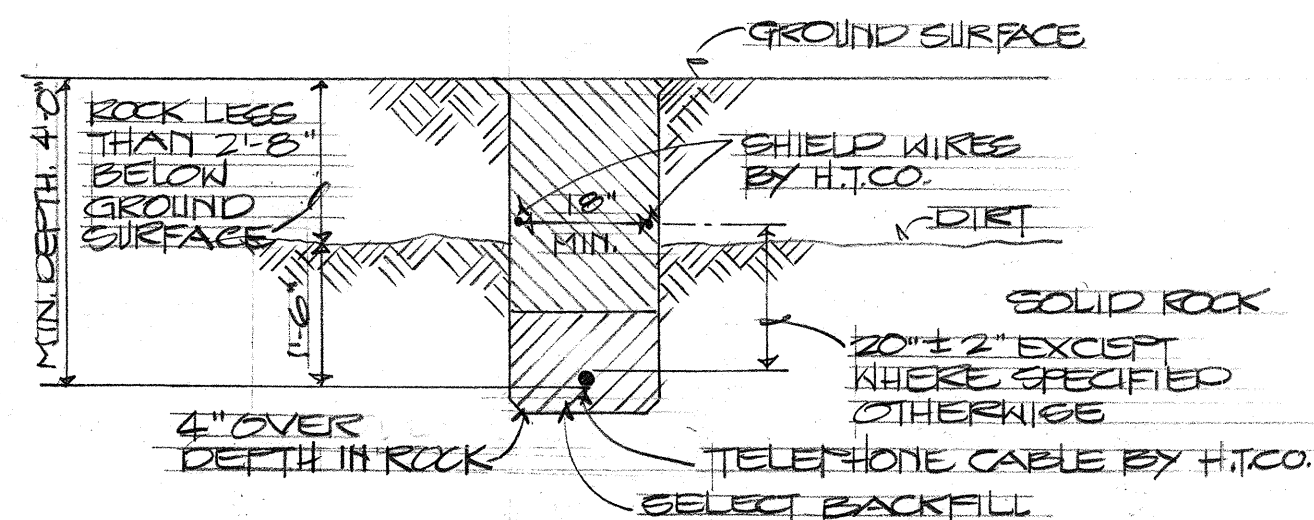

C
E-8
TYPICAL SECTION THROUGH TRENCH WITH ROCK LESS THAN 2'-6" BELOW SURFACE
NOT TO SCALE

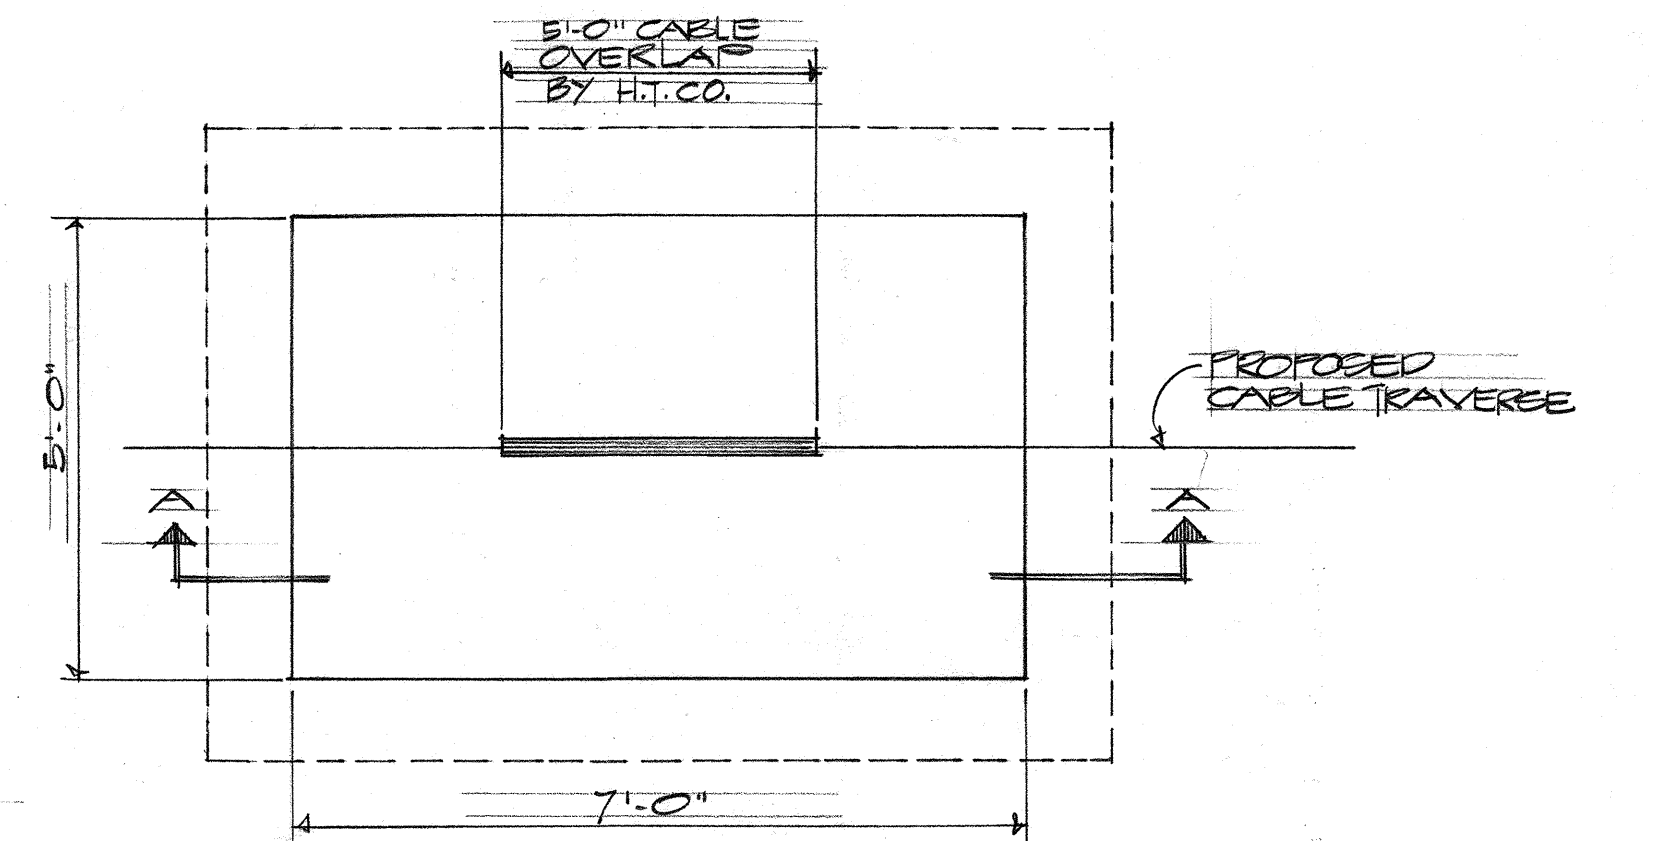


D
E-8
TYPICAL SECTION THROUGH TRENCH WITH ROCK 2'-6" TO 4'-0" BELOW SURFACE
NOT TO SCALE

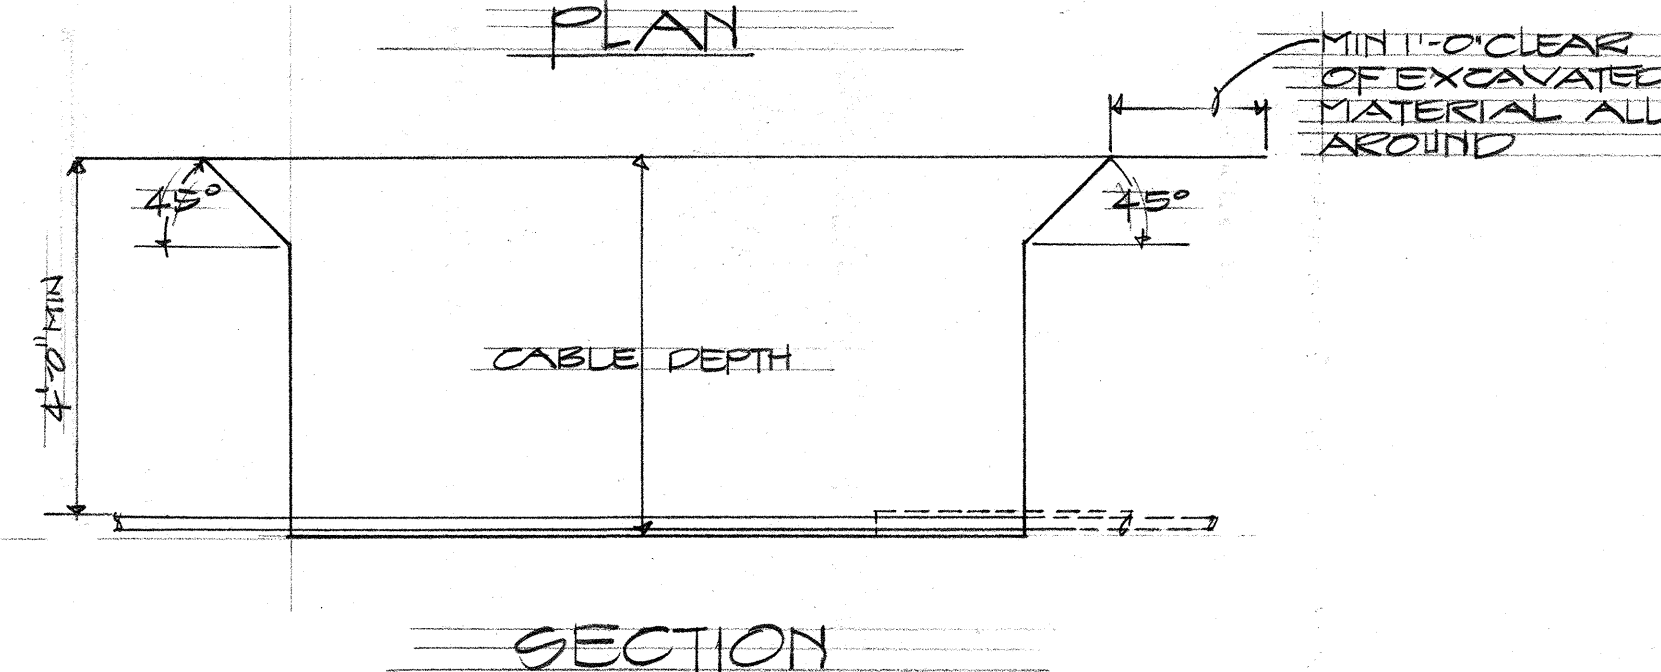


E
E-8
TYPICAL SPlicing PIT FOR BURIED CABLE
NOT TO SCALE

- NOTES:**
- THE CONTRACTOR SHALL DIG PITS AT SPECIFIED LOCATIONS.
 - ONE FACE OF PIT SHALL BE KEPT FREE OF EXCAVATED MATERIAL.
 - WHERE PITS ARE LOCATED ON SLOPING OR IRREGULAR GROUND THE EXCAVATED MATERIAL SHALL BE PLACED IN SUCH A MANNER AS TO PREVENT SURFACE WATER FROM DRAINING INTO THE PIT.

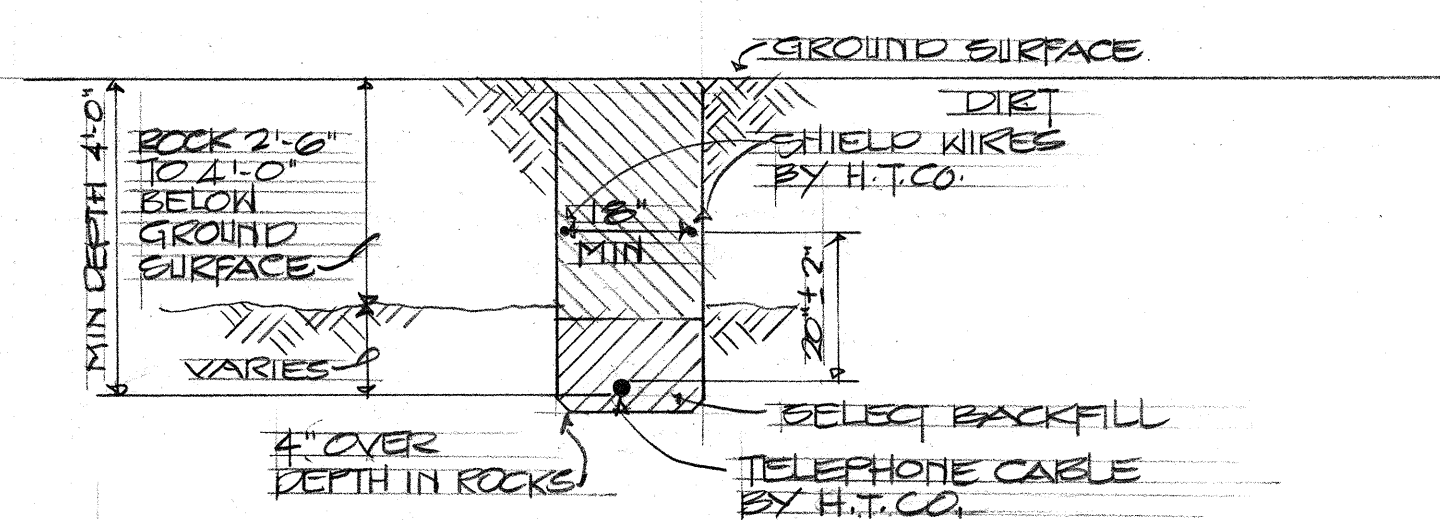

F
E-8
TYPICAL SECTION THROUGH TRENCH WITH ROCK 2'-6" TO 4'-0" BELOW SURFACE
NOT TO SCALE


DATE	DESIGNED BY	CHECKED BY
PLAN	DESIGNED BY	CHECKED BY
NOTE BOOK	DESIGNED BY	CHECKED BY
NO.	DESIGNED BY	CHECKED BY

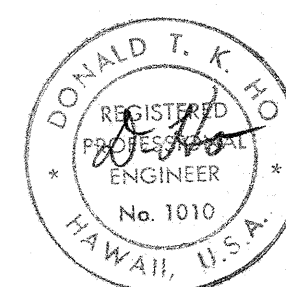

APPROVED BY: Donald T. K.
HAWAIIAN TELEPHONE CO. DATE: 6-25-69


STATE OF HAWAII
DEPARTMENT OF TRANSPORTATION
HIGHWAYS DIVISION
WAIKAWA INTERCHANGE
TELEPHONE DETAILS
F.A.I. Proj. No. I-H-1(75):8
Scales: As Shown Date:
SHEET No. E8 OF 17 SHEETS

FED. ROAD DIST. NO.	STATE	FED. AID PROJ. NO.	FISCAL YEAR	SHEET NO.	TOTAL SHEETS
HAWAII	HAW.	I-HI-1(75):8	1969	59	181

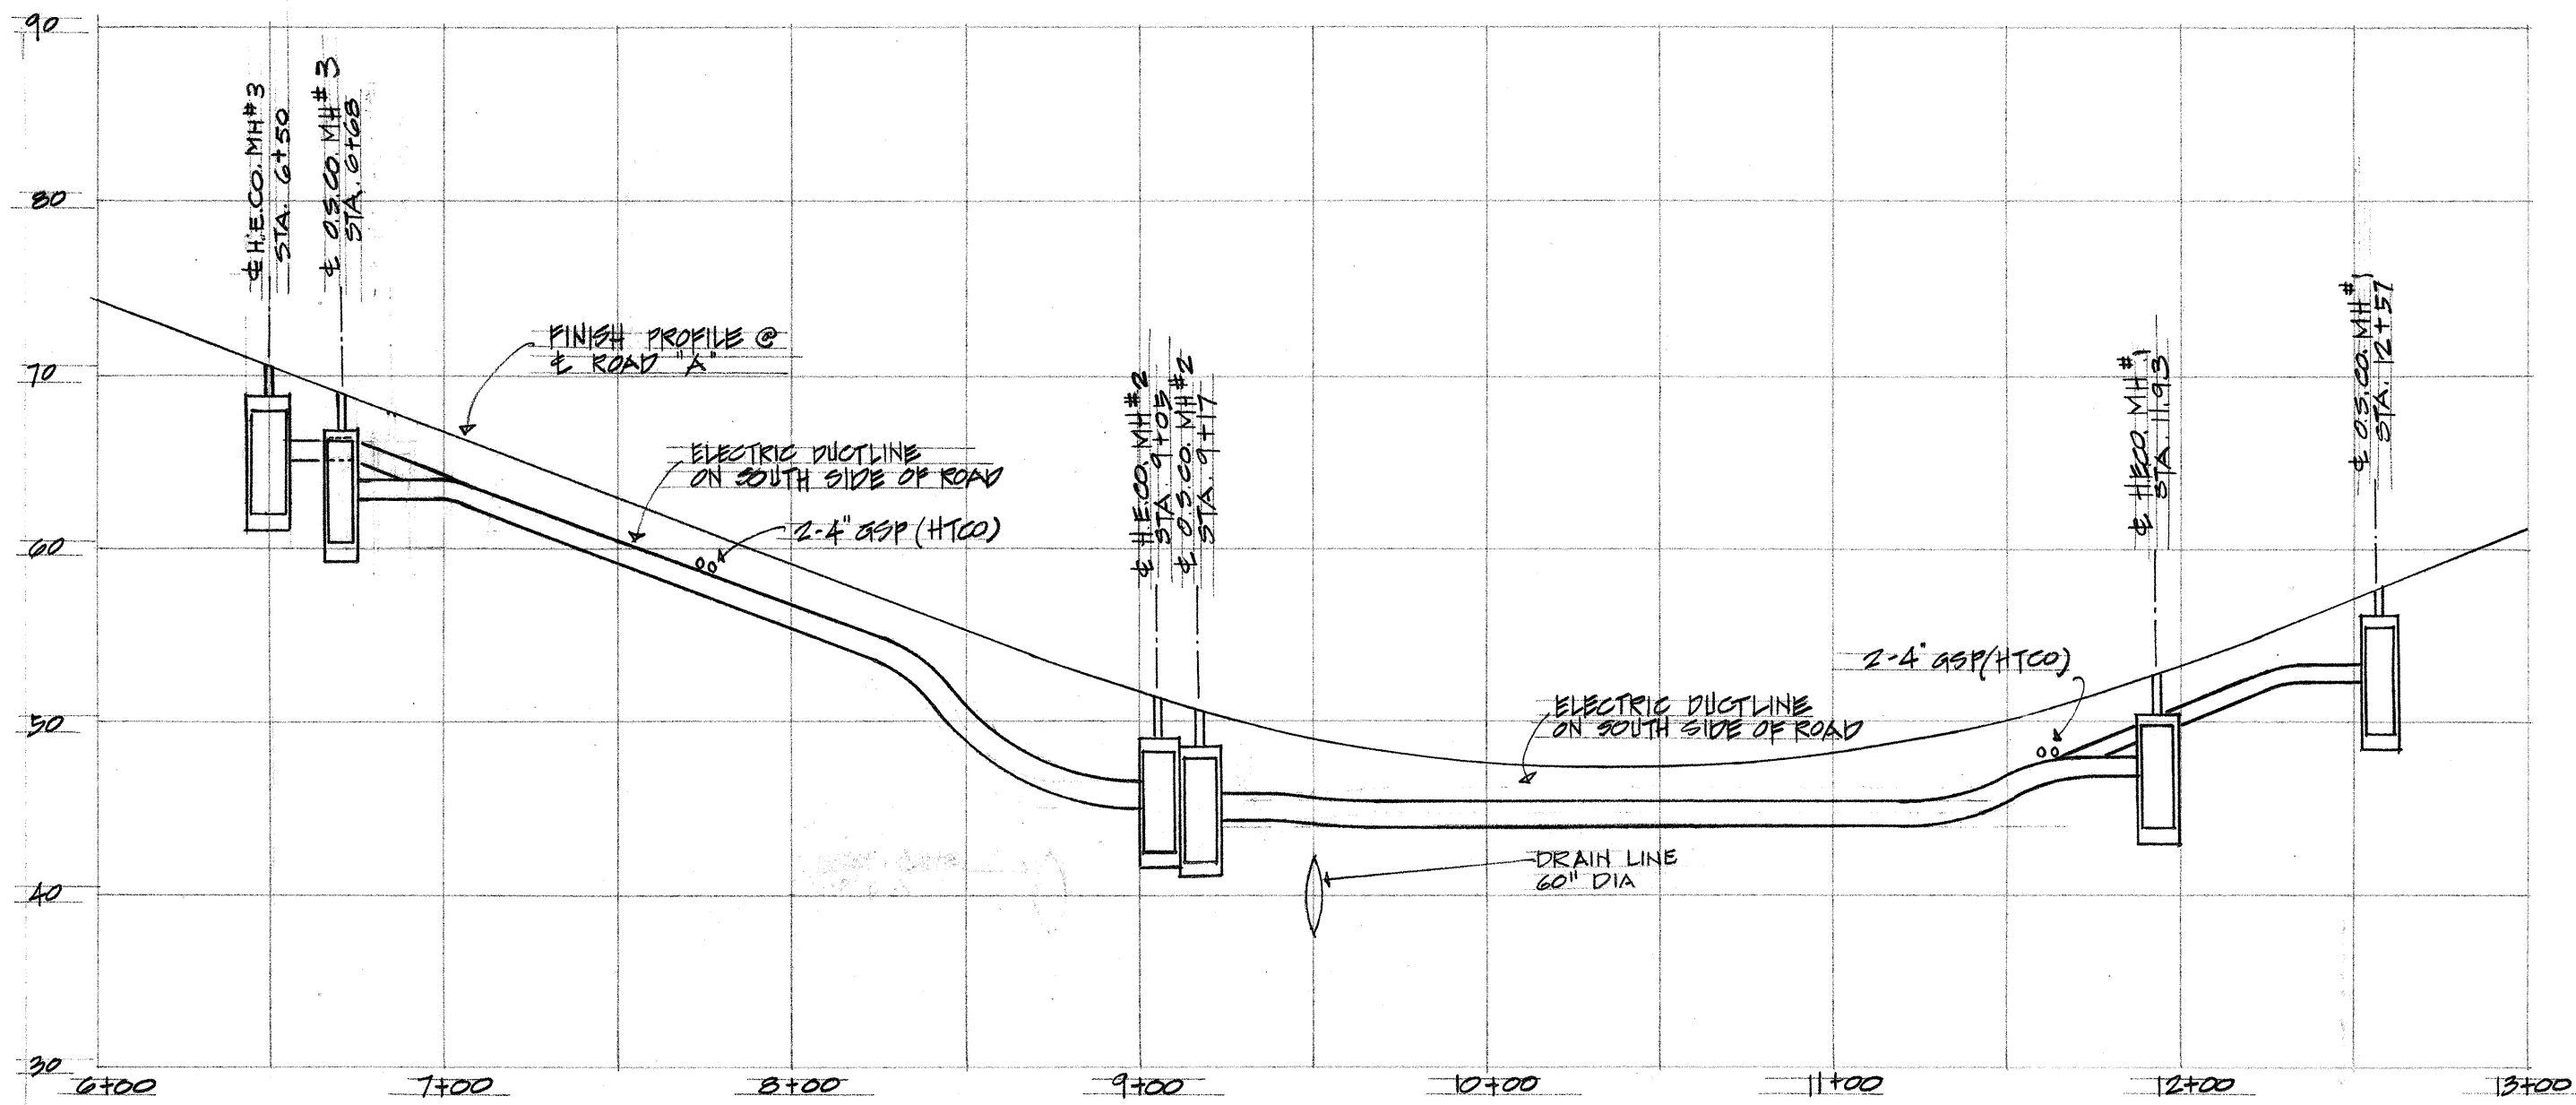


PROFILE-ELECTRICAL DUCTLINE ON SOUTH SIDE OF
CANE HAULING ROAD A STATION 6+00 TO 13+00

SCALE: HOR. 1"=50'
VERT. 1"=10'

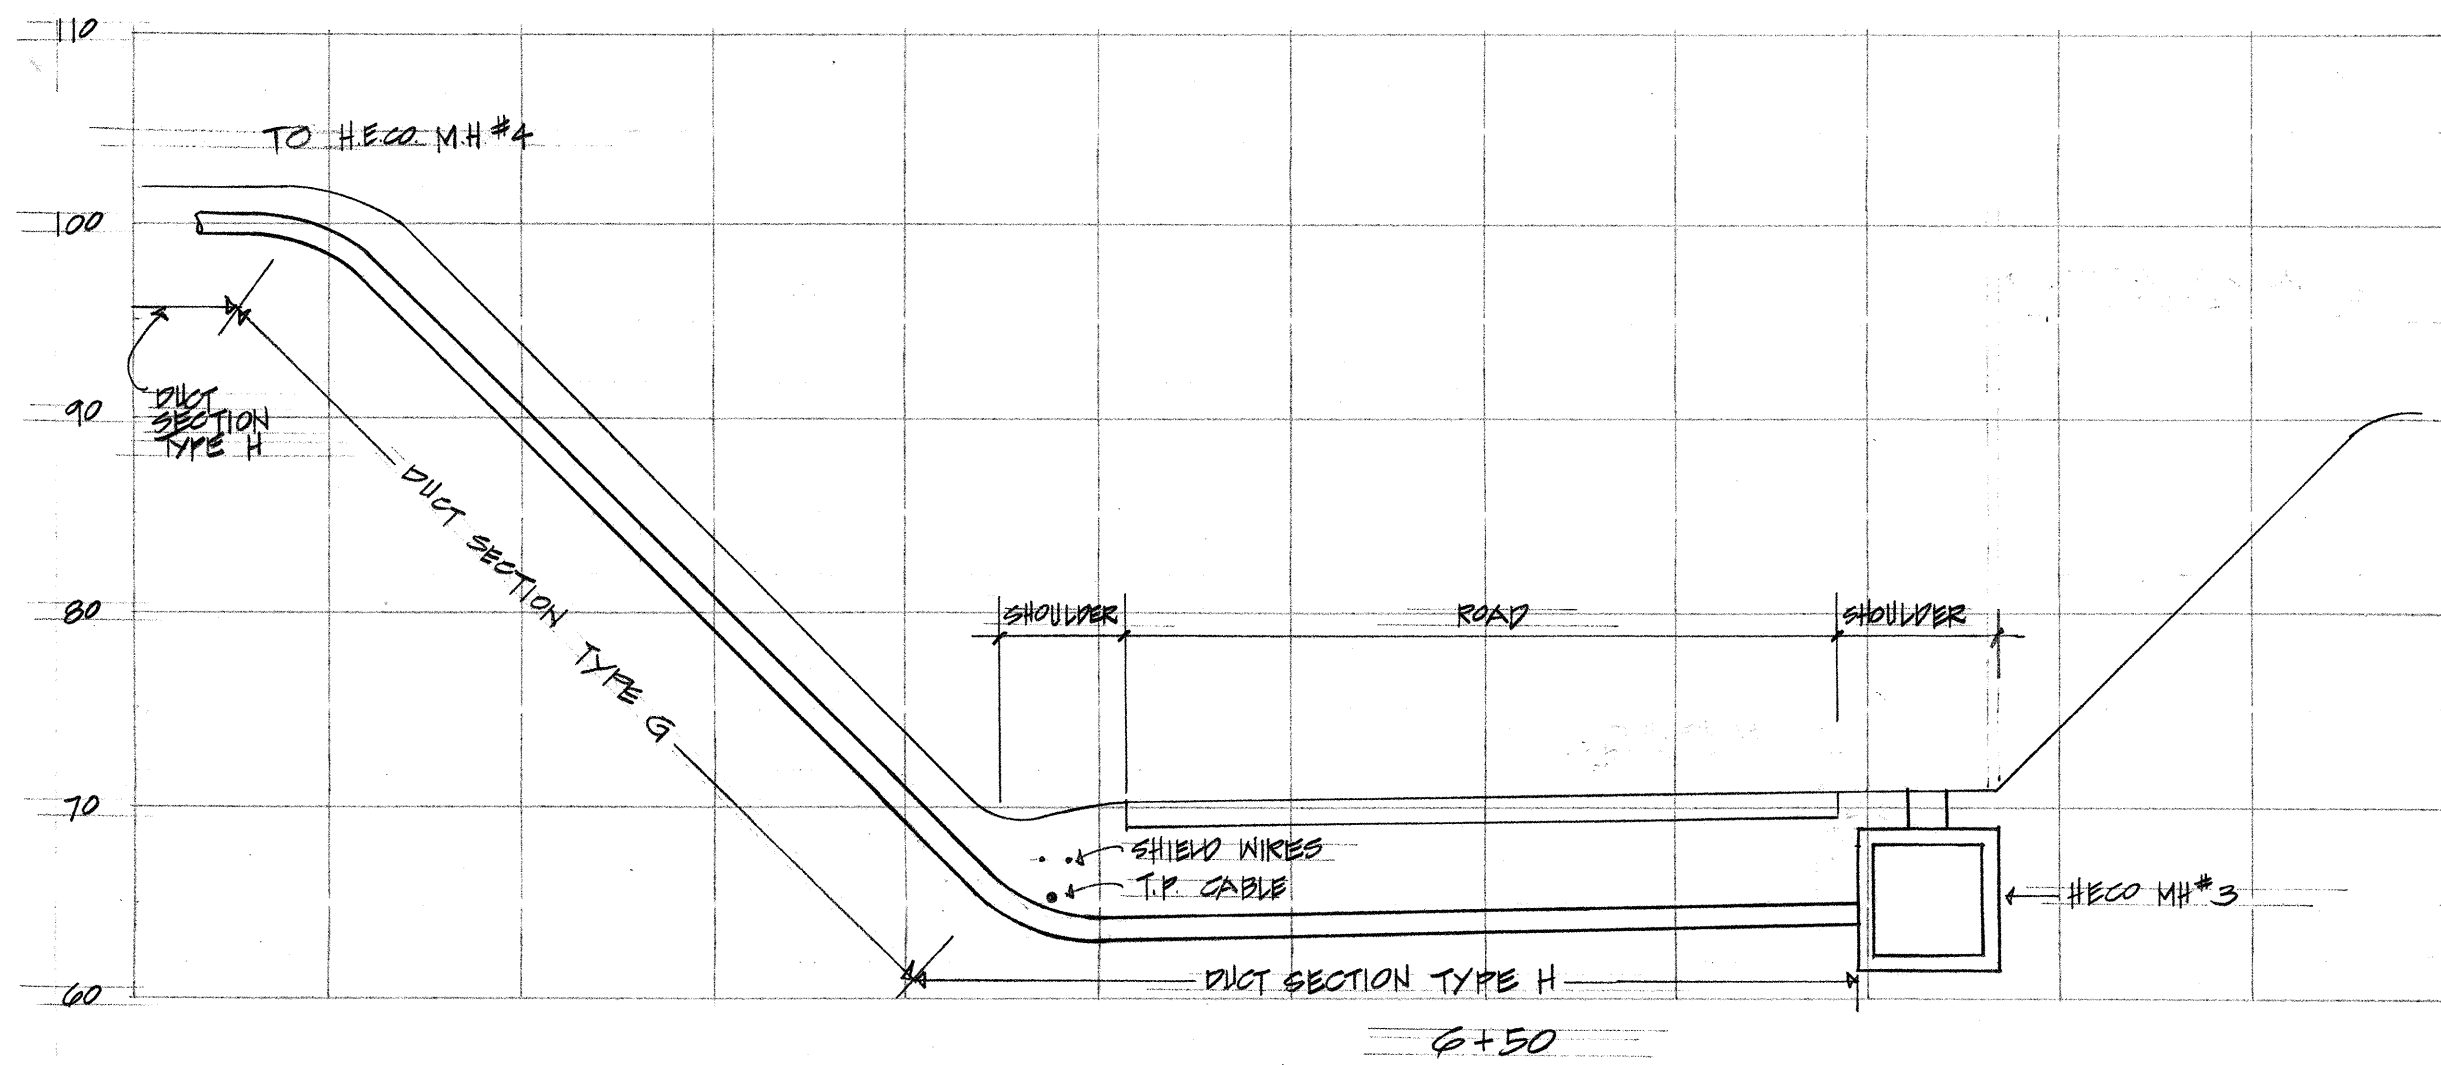

PROFILE-ROAD CROSSING AT STATION
6+50 CANE HAULING ROAD A


SCALE: 1"=10'

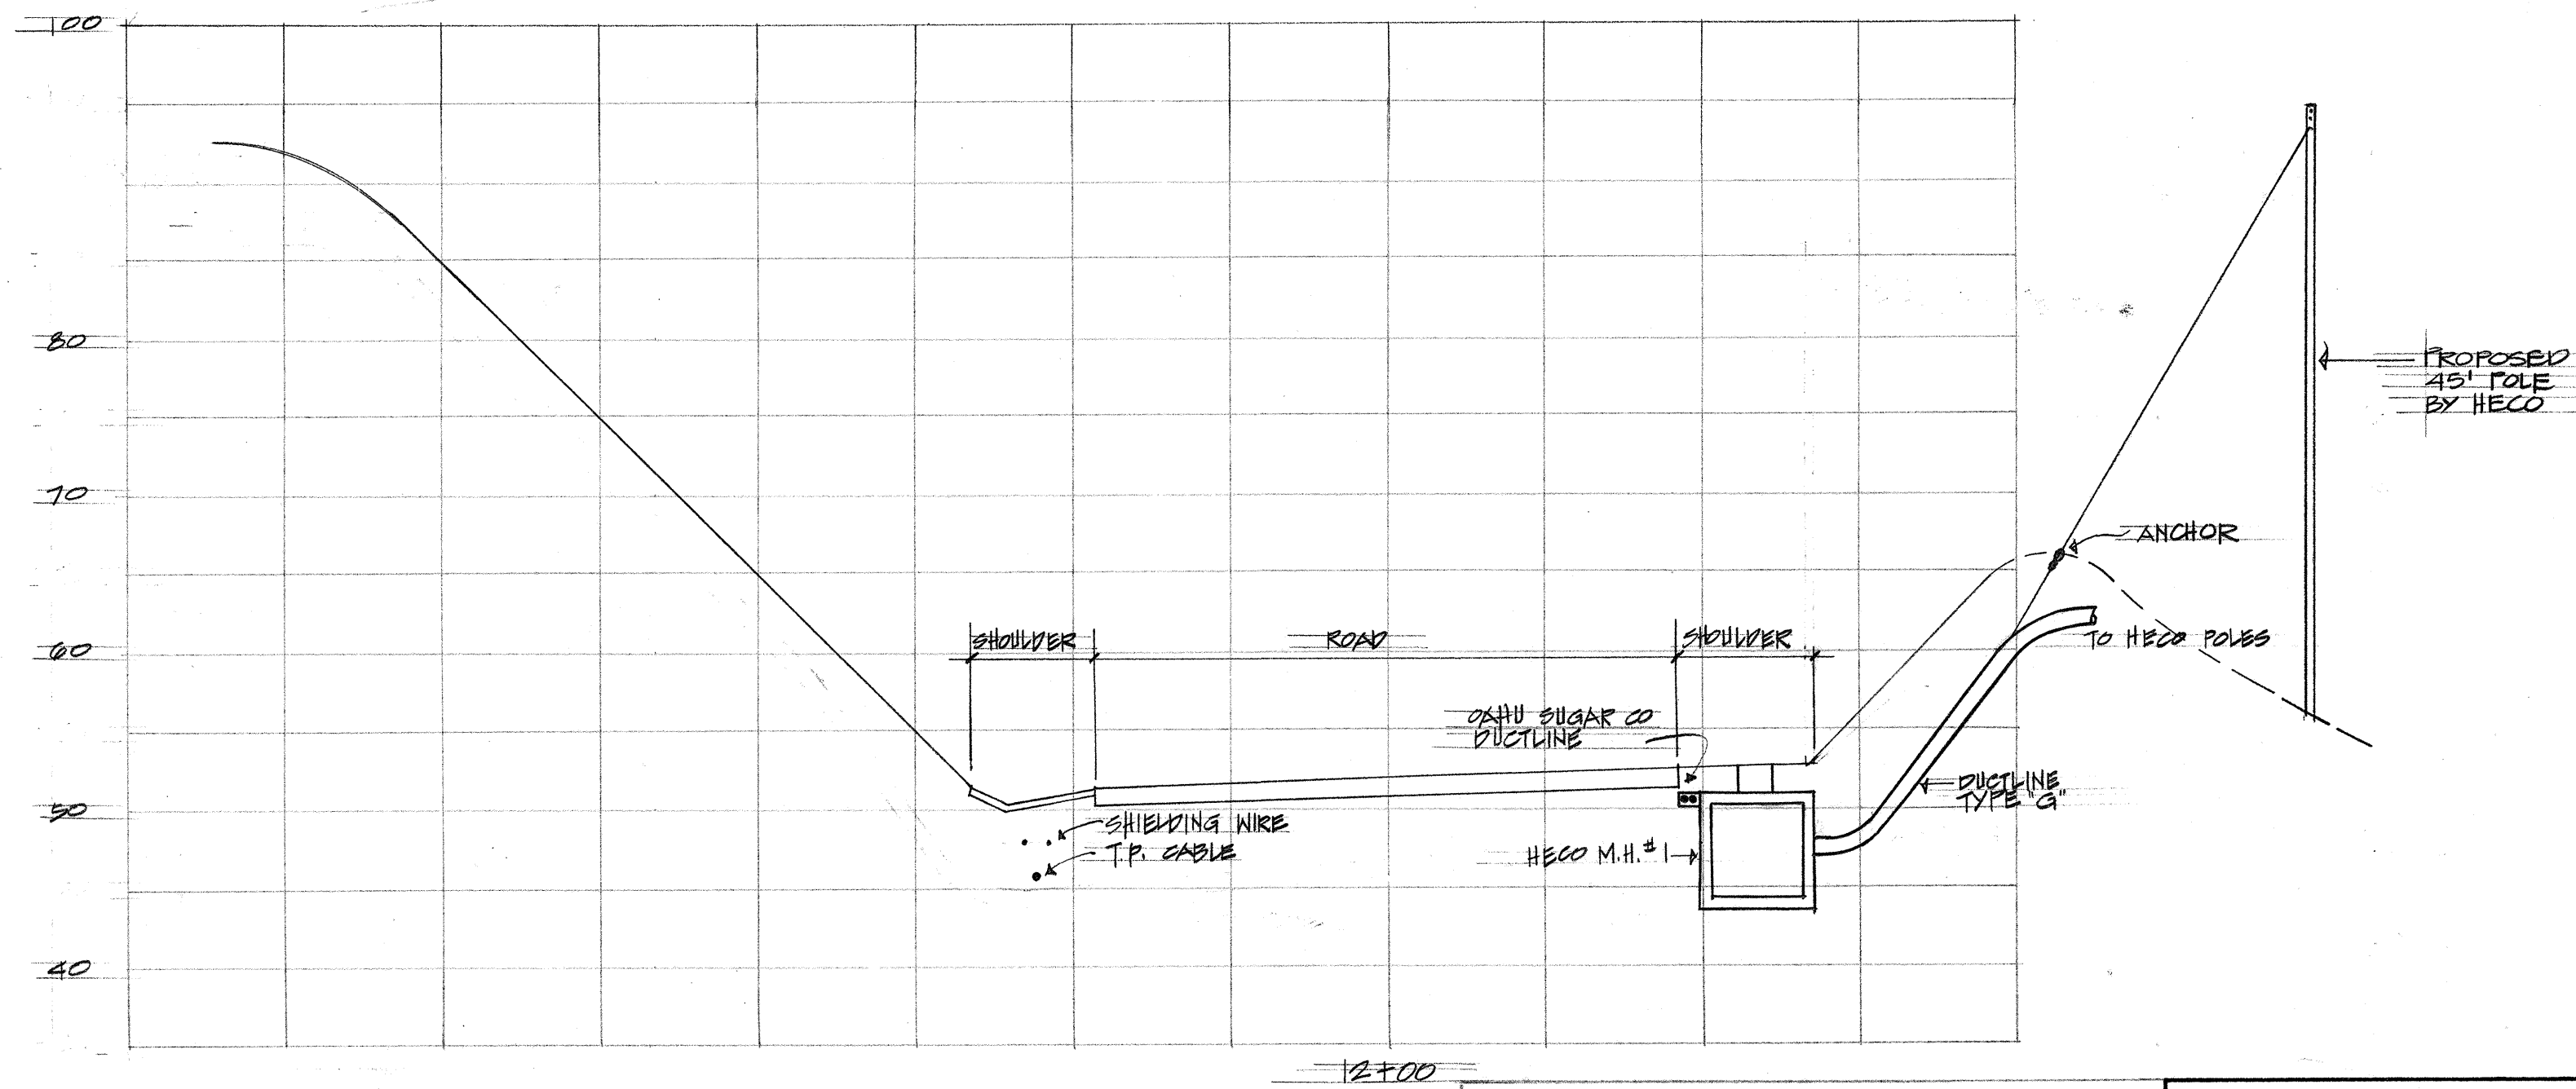

PROFILE-ROAD CROSSING AT STATION
12+00 CANE HAULING ROAD

SCALE: 1"=10'

THIS WORK WAS PREPARED BY
ME OR UNDER MY SUPERVISION,

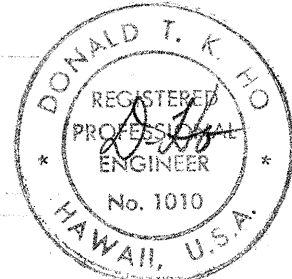

APPROVED BY:

J. J. [Signature] 6-28-69
HAWAIIAN TELEPHONE CO DATE
W. K. [Signature] 7-29-69
HAWAIIAN ELECTRIC CO DATE
RN JK

STATE OF HAWAII
DEPARTMENT OF TRANSPORTATION
HIGHWAYS DIVISION
WAI'ANA INTERCHANGE


DUCTLINE PROFILES

F.A.I. Proj. No I-HI-1 (75): 8
Scale: AS SHOWN Date:


SHEET No. E-9 OF 17 SHEETS

SURVEY PLOTTED BY	DATE
DRAWN BY	
DESIGNED BY	
QUANTITIES BY	
CHECKED BY	
ORIGINAL PLAN	
NOTE BOOK	
No.	


FED. ROAD DIST. NO.	STATE	FED. AID PROJ. NO.	FISCAL YEAR	SHEET NO.	TOTAL SHEETS
HAWAII	HAW.	1-HI-1(75):8	1969	60	181

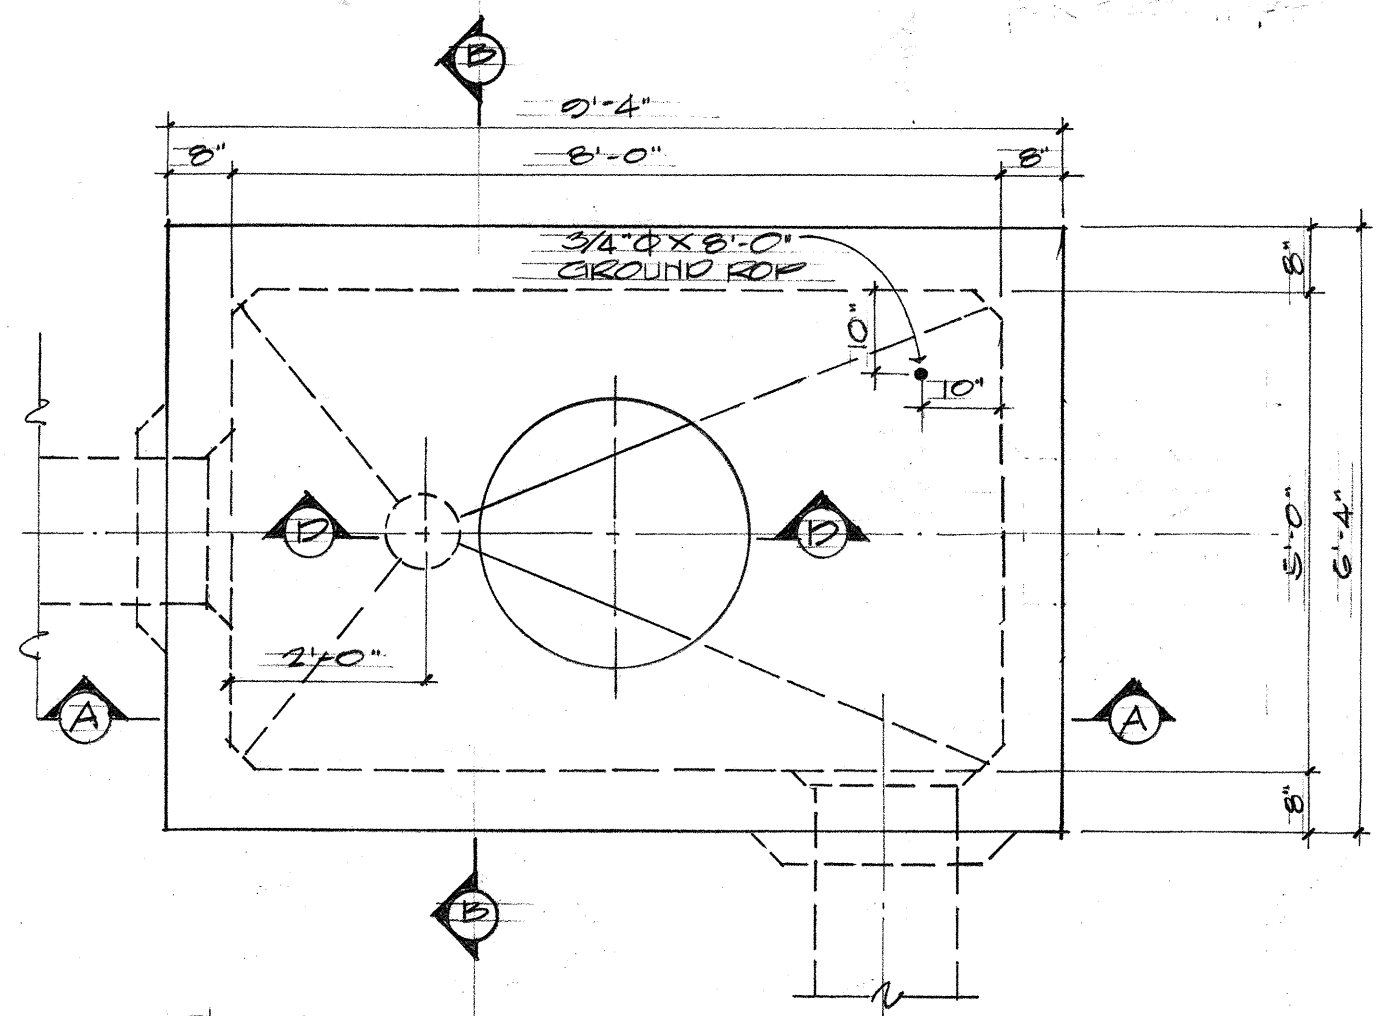


PLAN
SCALE: 1/2"=1'-0"

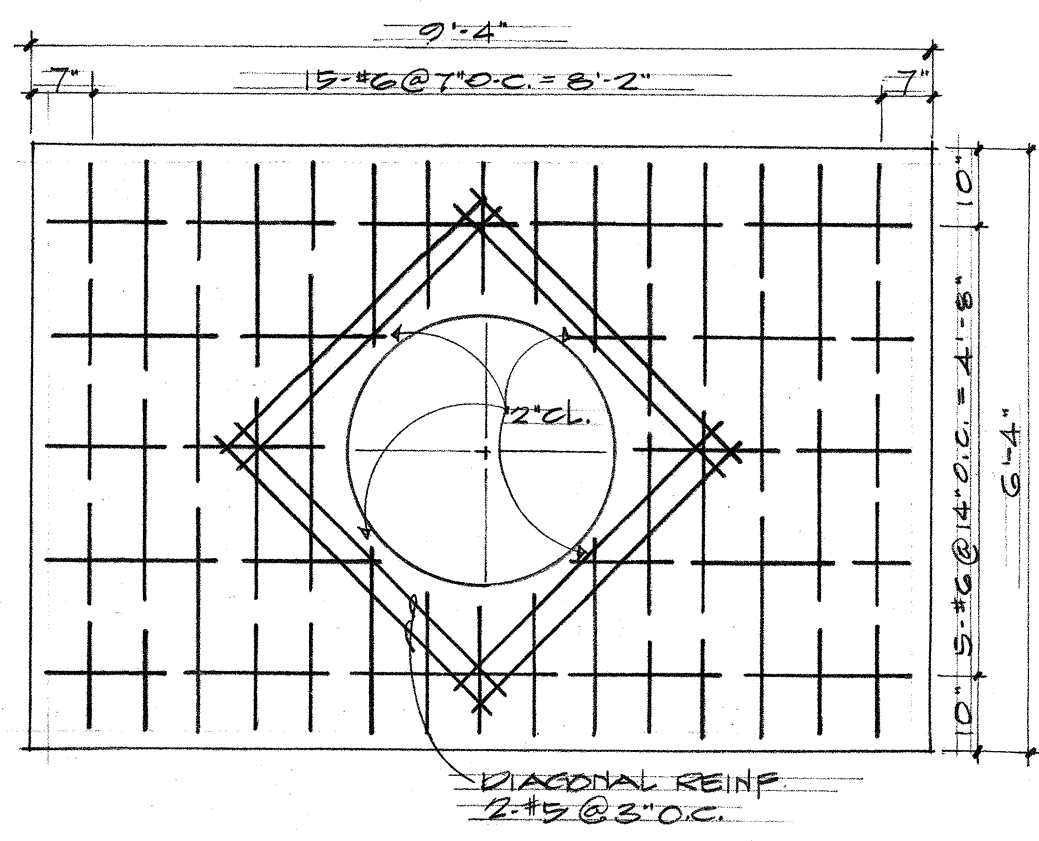


ROOF SLAB REINF. PLAN
SCALE: 1/2"=1'-0"

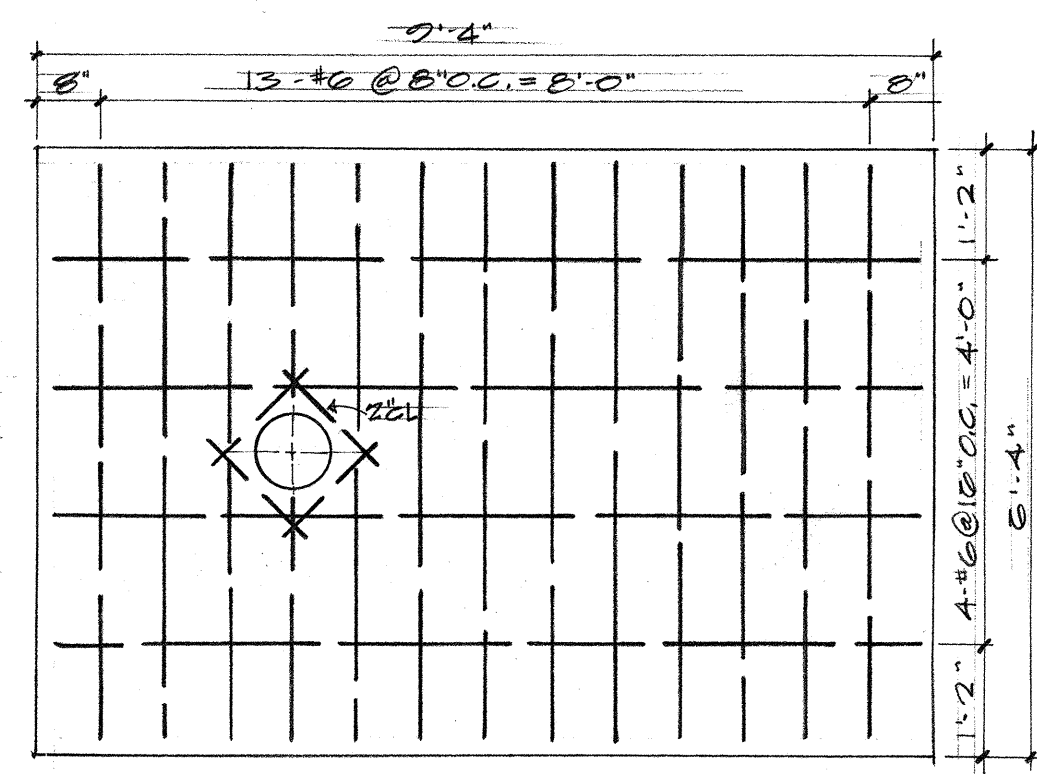


FLOOR SLAB REINF. PLAN
SCALE: 1/2"=1'-0"

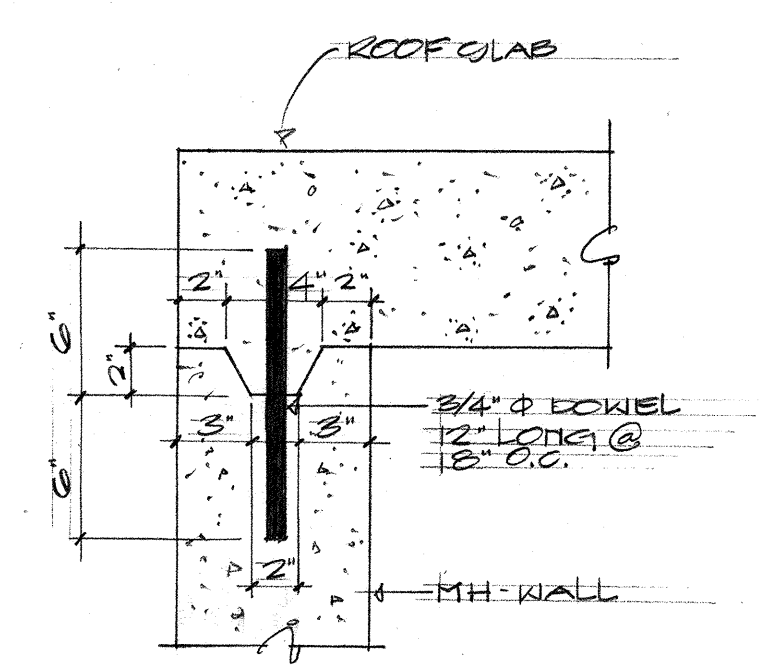


DETAIL "A"
TOP CONSTR. JOINT
OPTIONAL FOR CAST-IN-PLACE CONSTR.
REQUIRED FOR PRECAST CONSTR.
SCALE: 1 1/2"=1'-0"

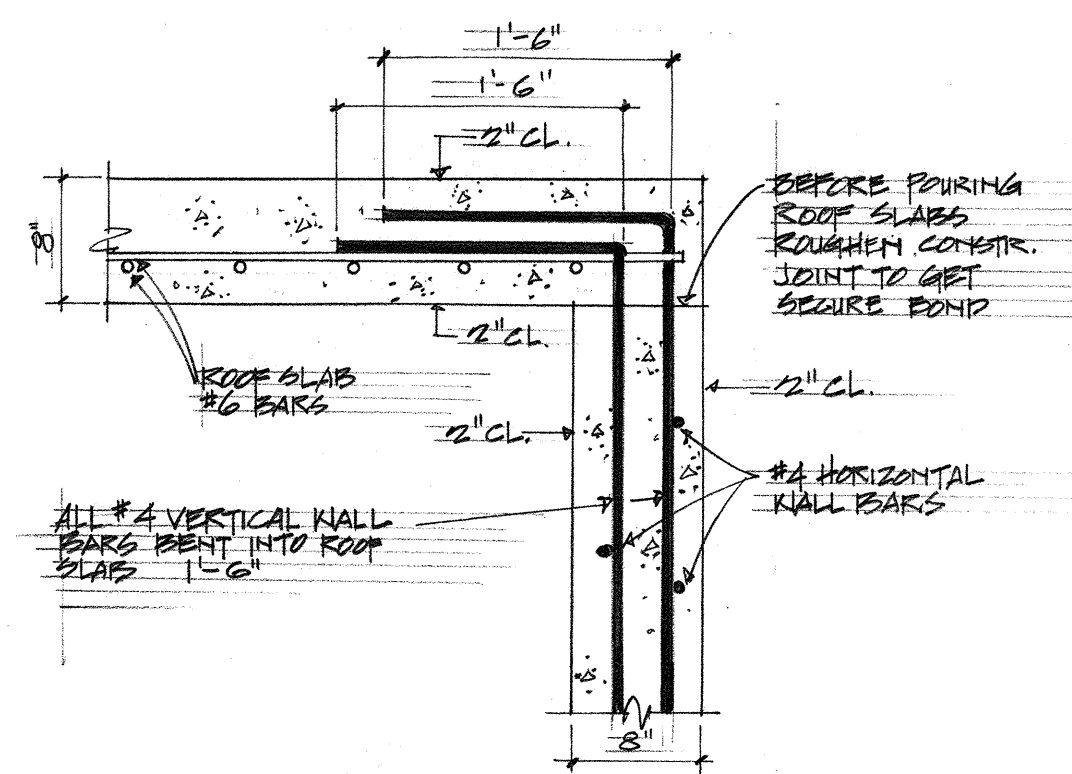


CONSTR. JOINT DETAIL "B"
USE FOR CAST-IN-PLACE CONSTR.
SCALE: 1"=1'-0"

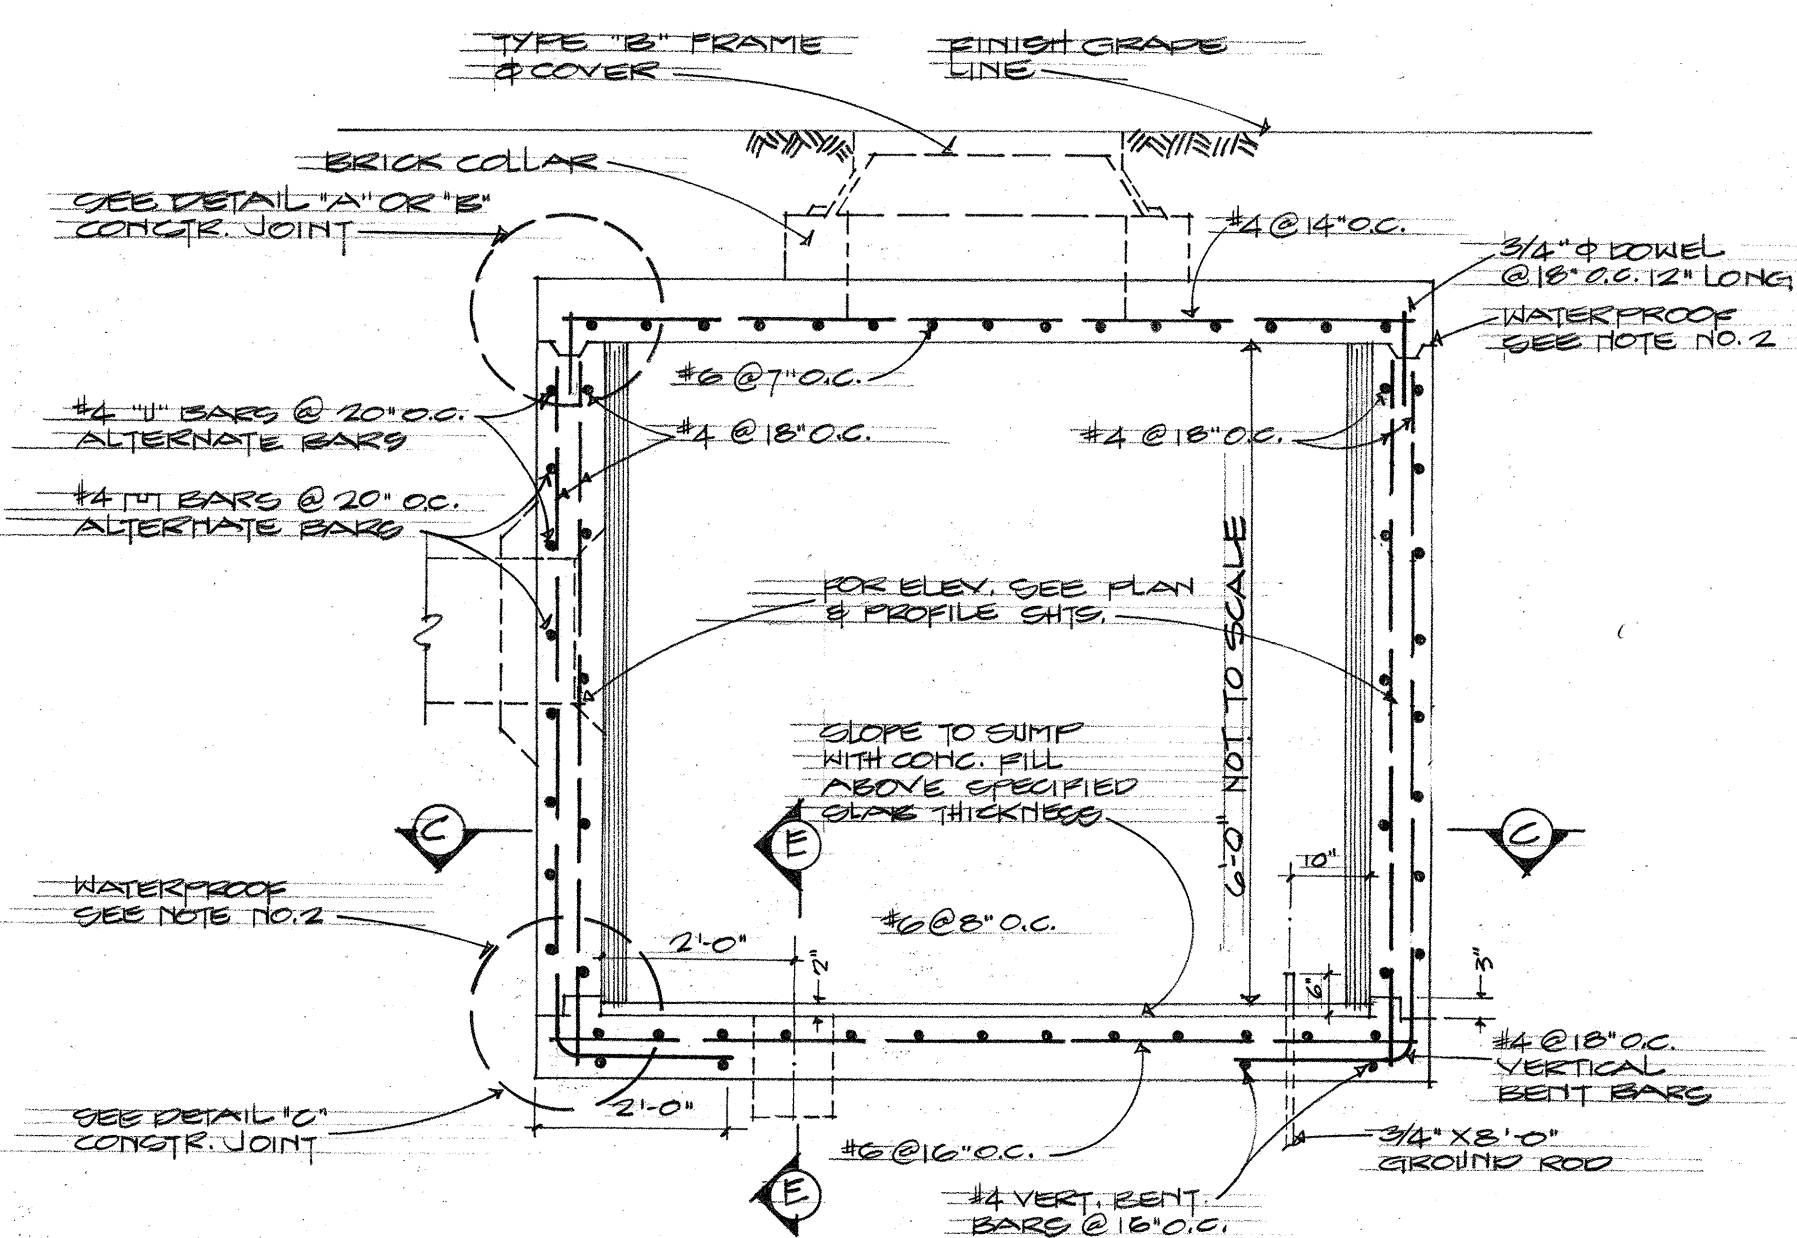


SECTION "A-A"
SCALE: 1/2"=1'-0"

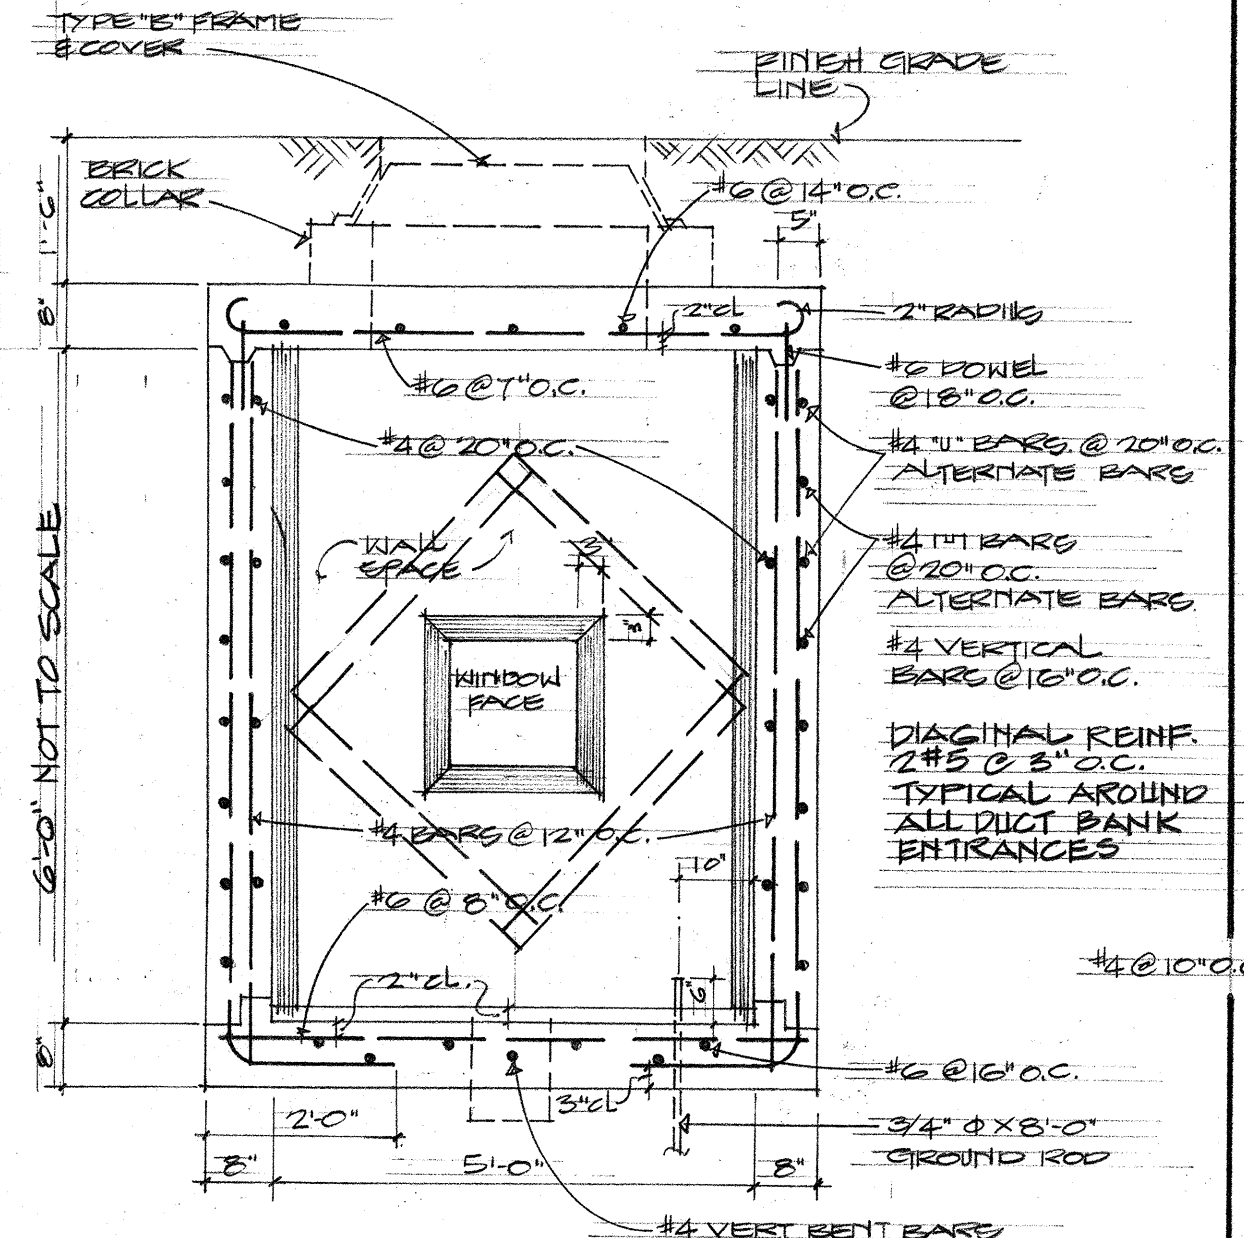

SECTION "B-B"
SCALE: 1/2"=1'-0"

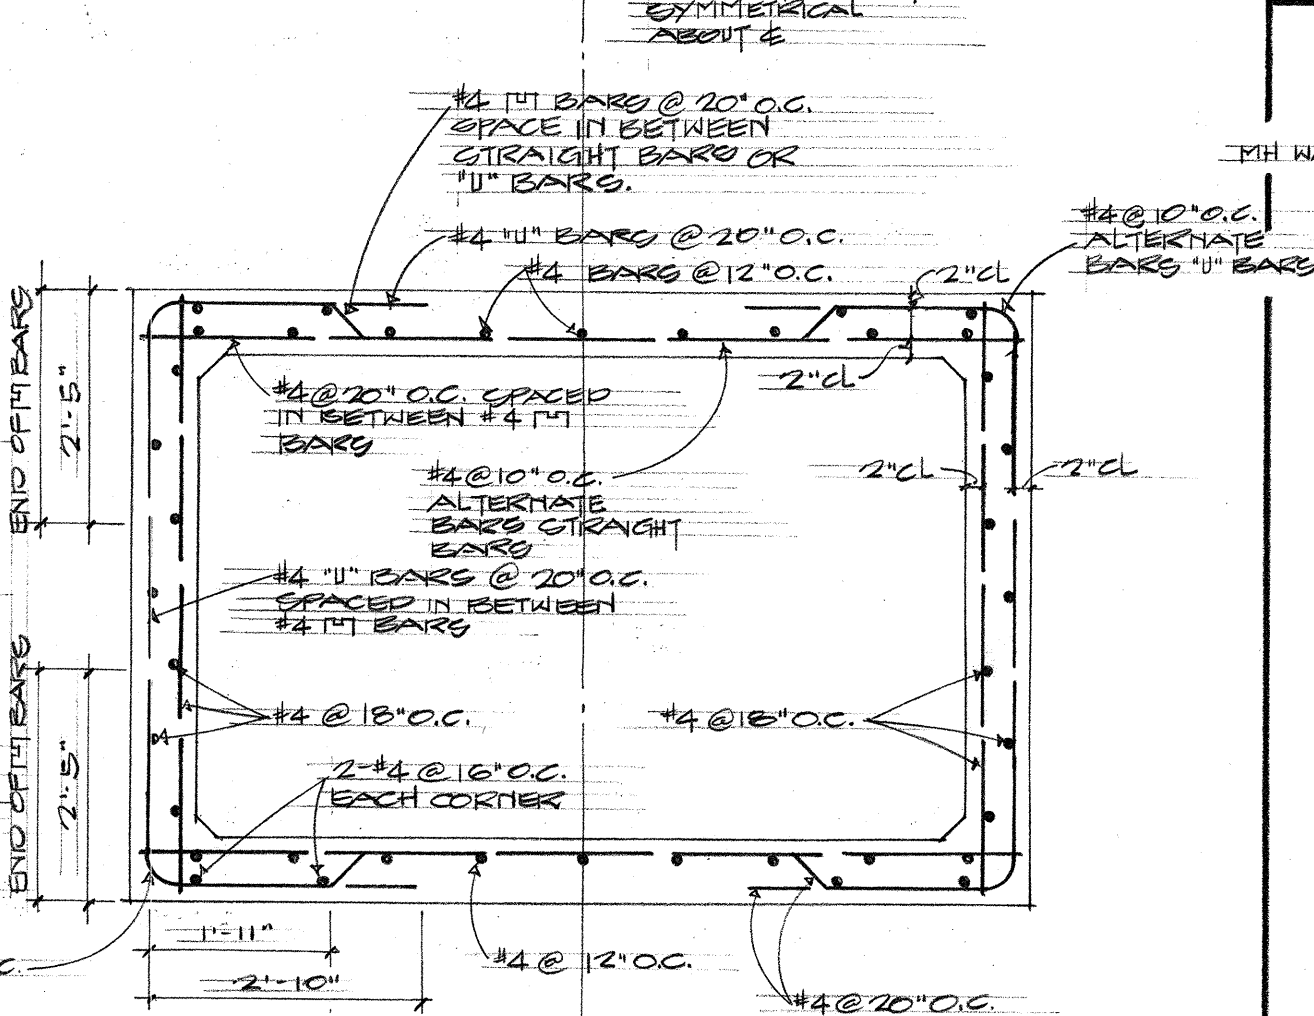


SECTION "C-C"
SCALE: 1/2"=1'-0"

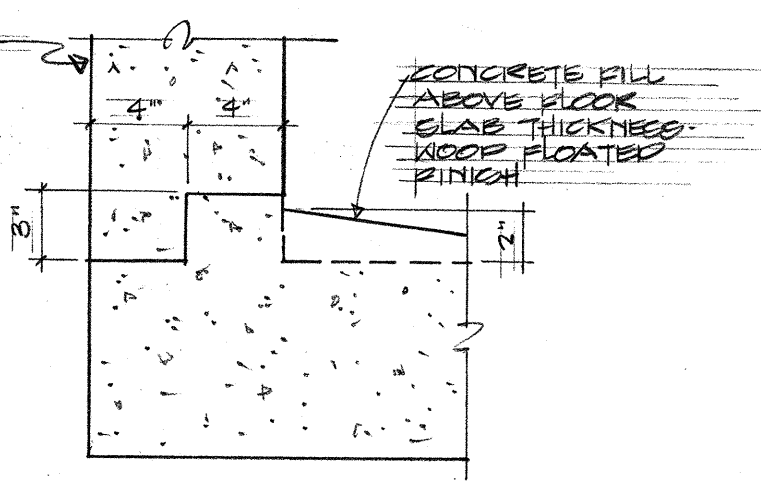


DETAIL "C"
BOTTOM CONSTR. JOINT
SCALE: 1 1/2"=1'-0"

GENERAL NOTES:


- DESIGN DATA:
F_s = 20,000 PSI
F_c = 3,000 PSI, F_c = 1350 PSI
n = 10
- ALL CONSTRUCTION JOINTS SHALL BE WATERPROOFED WITH TWO APPLICATIONS OF THORO SEAL OR EQUAL.
- DUCT WINDOW LOCATIONS TO MATCH INCOMING CONDUIT ELEVATION.
- DUCT WINDOW TO SUIT - SEE PLAN & PROFILE & STANDARD DETAIL SHEETS FOR LOCATION & DETAILS.

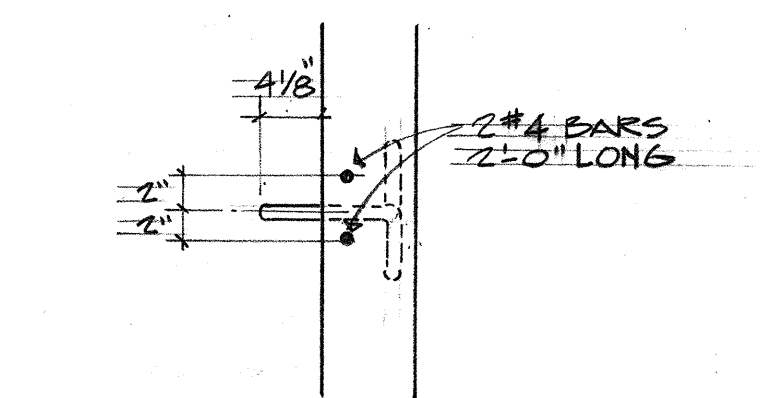


SECTION - PULLING-IN IRON

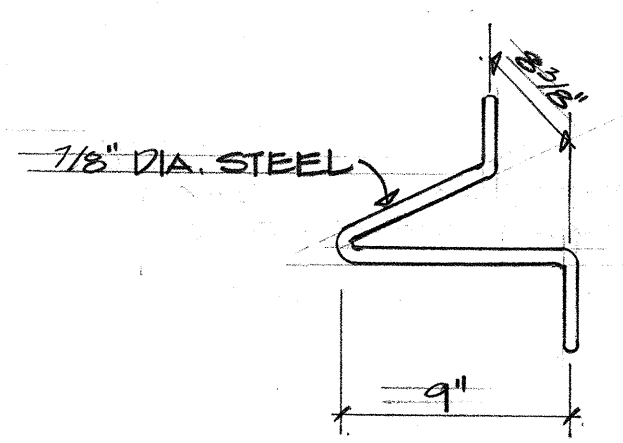


PULLING-IN IRON

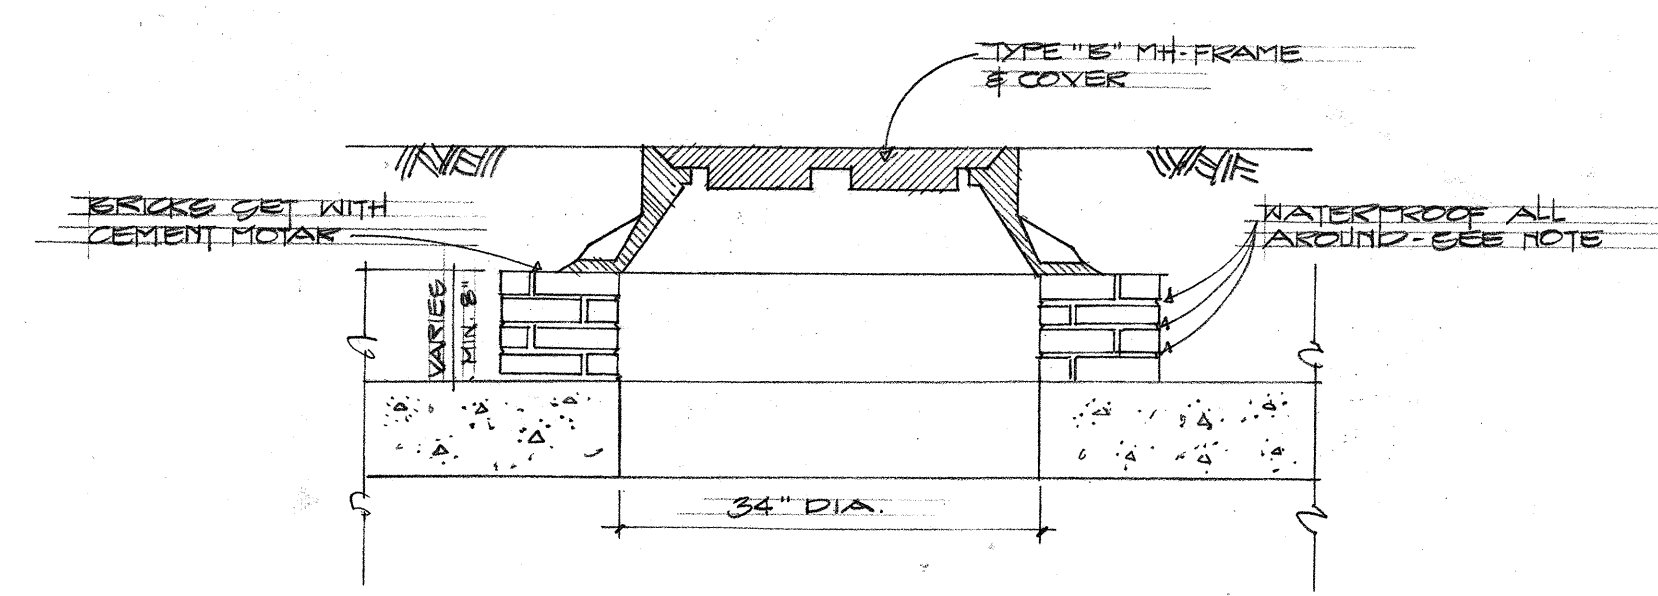

SECTION "D-D"
MH. COVER DETAIL
SCALE: 3/4"=1'-0"

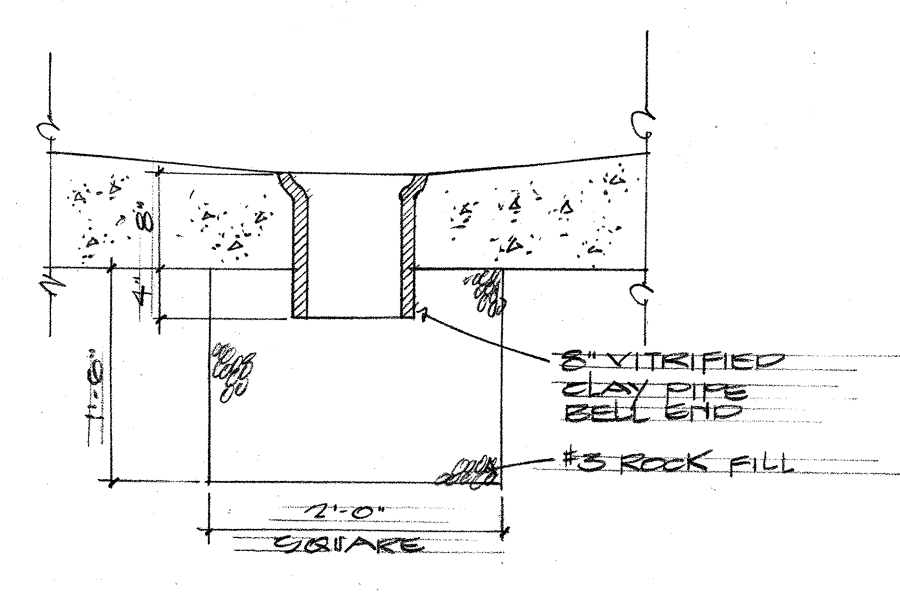

SECTION "E-E"
MH. SUMP DETAIL
SCALE: 3/4"=1'-0"

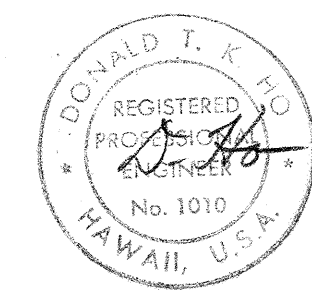


THIS WORK WAS PREPARED BY ME OR UNDER MY SUPERVISION.

STATE OF HAWAII
DEPARTMENT OF TRANSPORTATION
HIGHWAYS DIVISION
WAIKANA INTERCHANGE
MANHOLE DETAILS

F.A.I. Proj No. 1-HI-1(75):8
Scales: AS SHOWN


SHEET No. E-10 OF 17 SHEETS

FED. ROAD DIST. NO.	STATE	FED. AID PROJ. NO.	FISCAL YEAR	SHEET NO.	TOTAL SHEETS
HAWAII	HAW.	I-HI-1(75)-8	1969	62	181

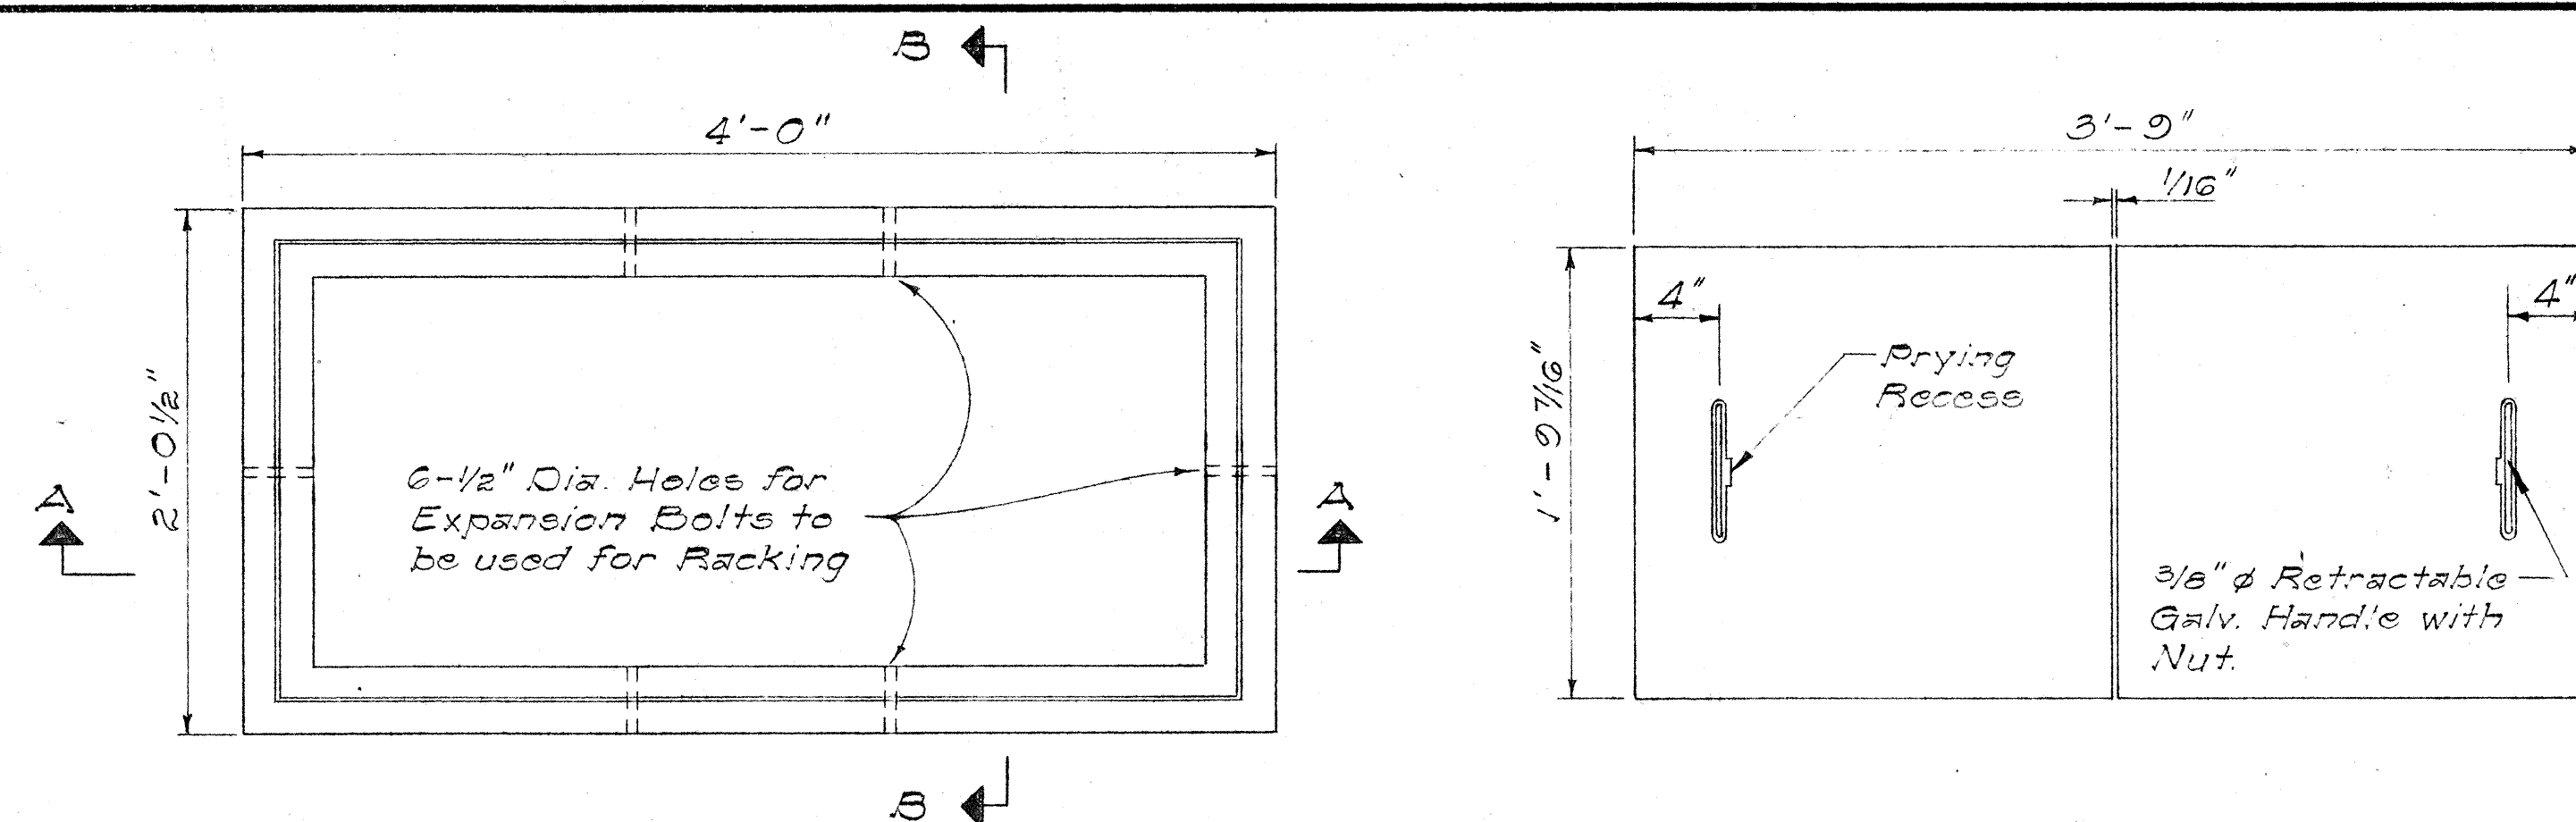


PLAN

PLAN OF COVER

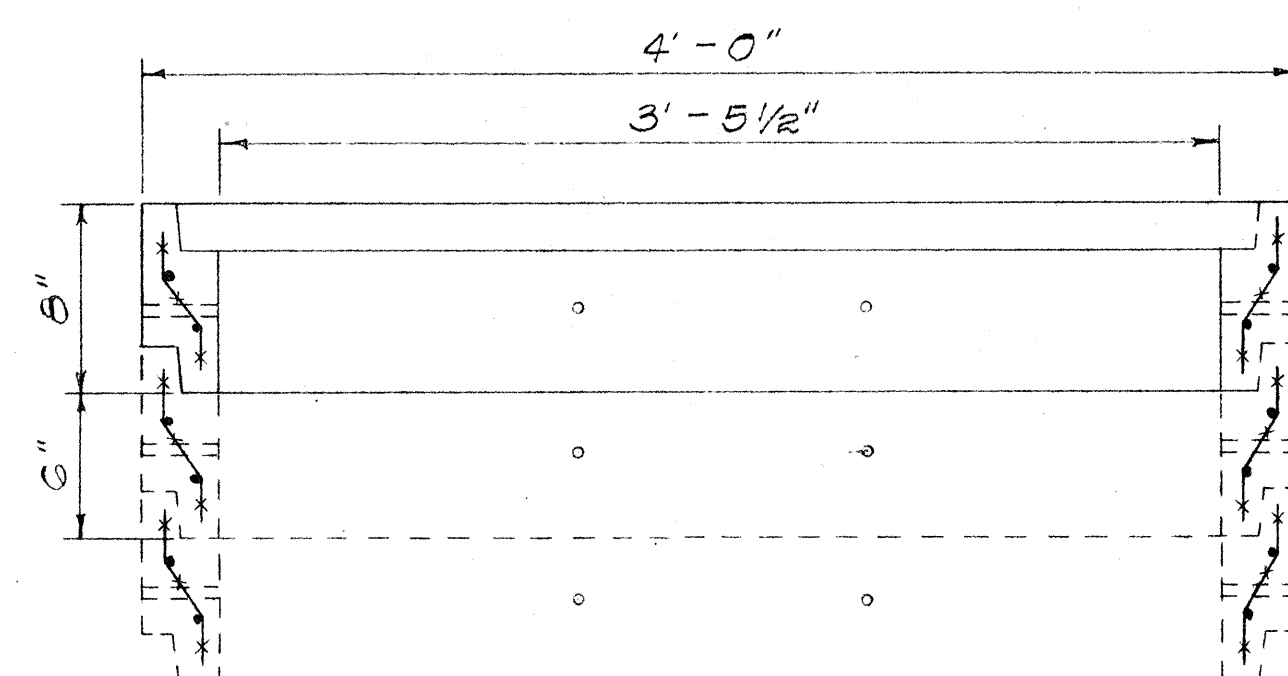


SECTION "A-A"

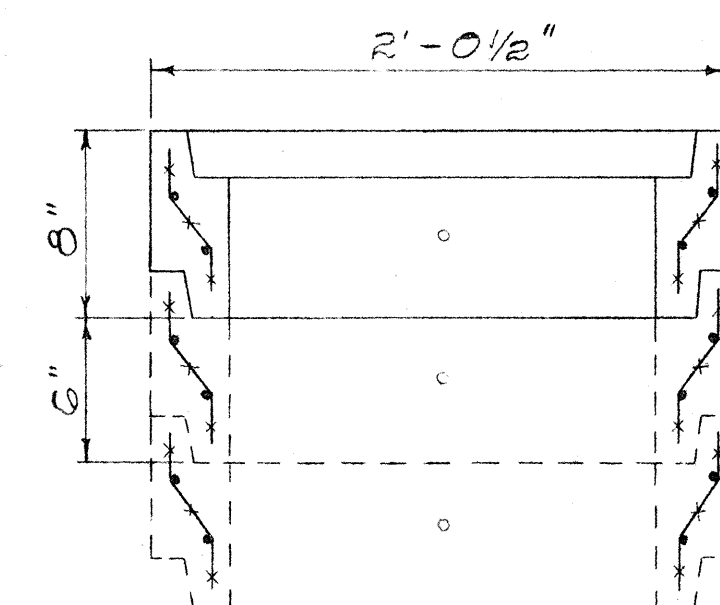

SECTION "B-B"


DETAIL OF LARGE PULL BOX No. 435T-B

Scale: 1 1/2" = 1'-0"

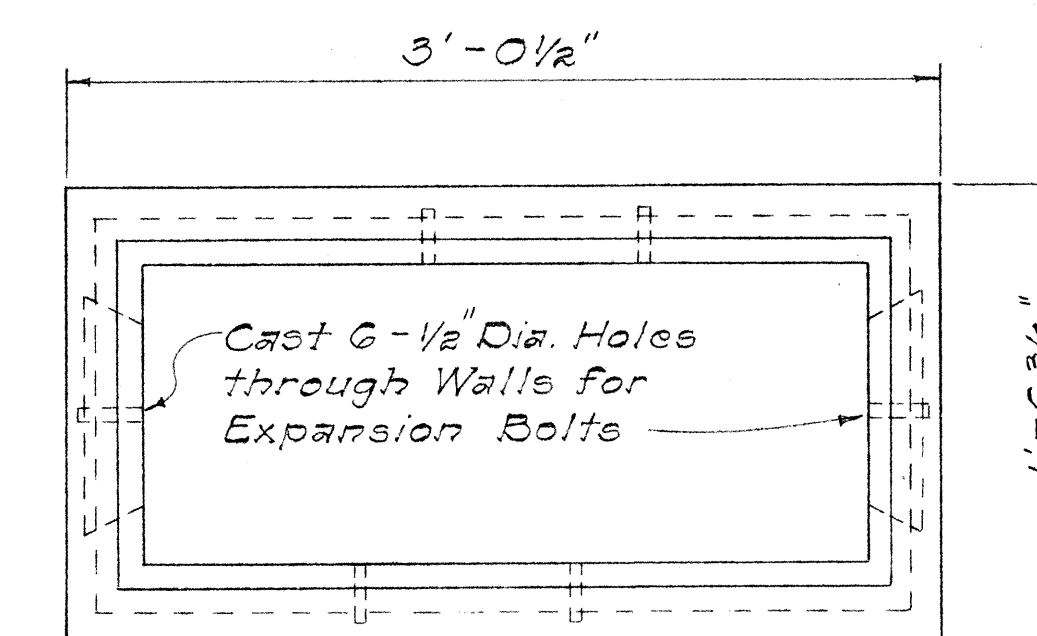


PLAN

PLAN OF COVER

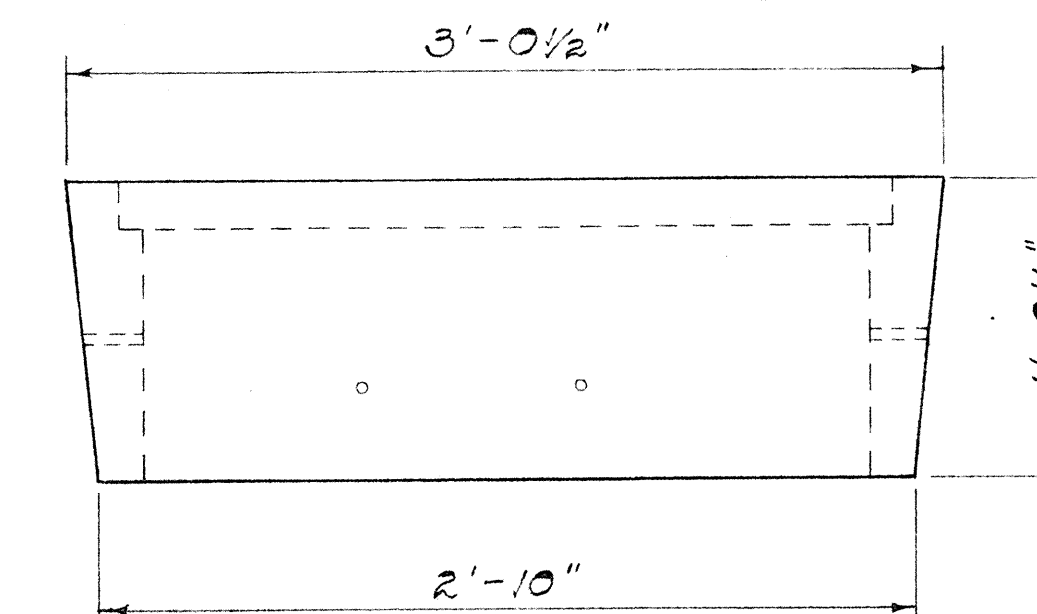


SIDE ELEVATION

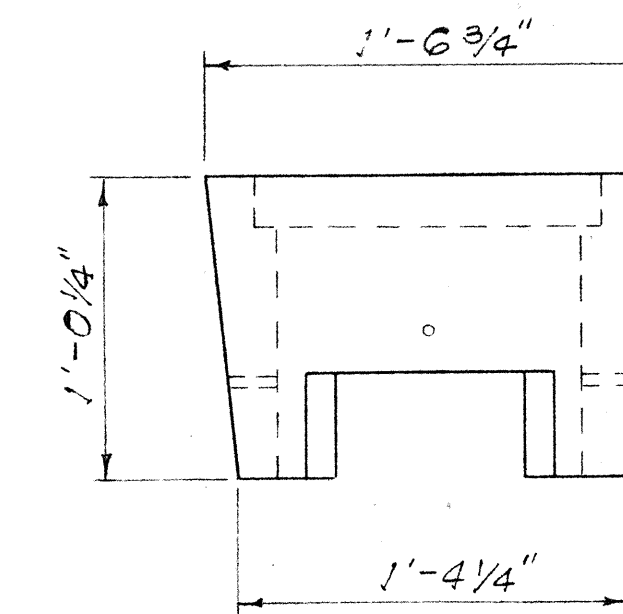


END ELEVATION

DETAIL OF SMALL PULL BOX No. 434T

Scale: 1 1/2" = 1'-0"

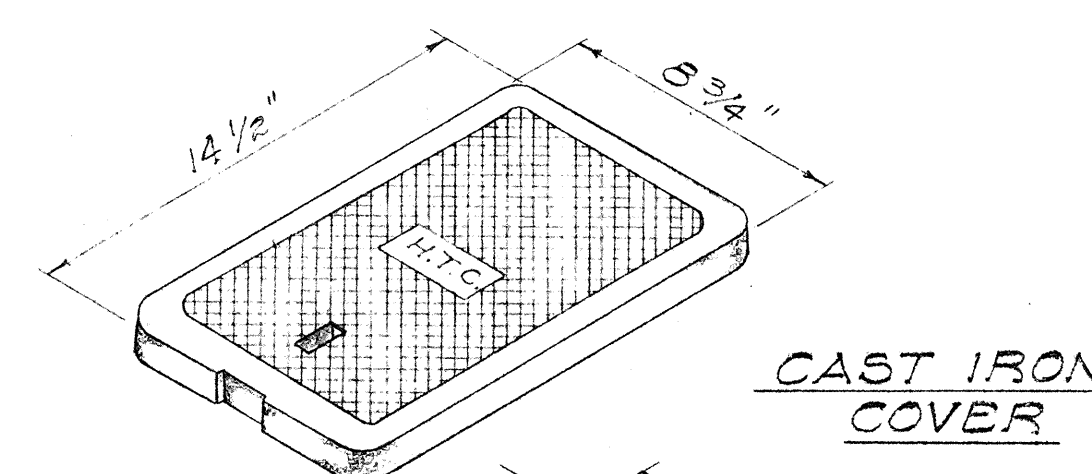


CAST IRON COVER

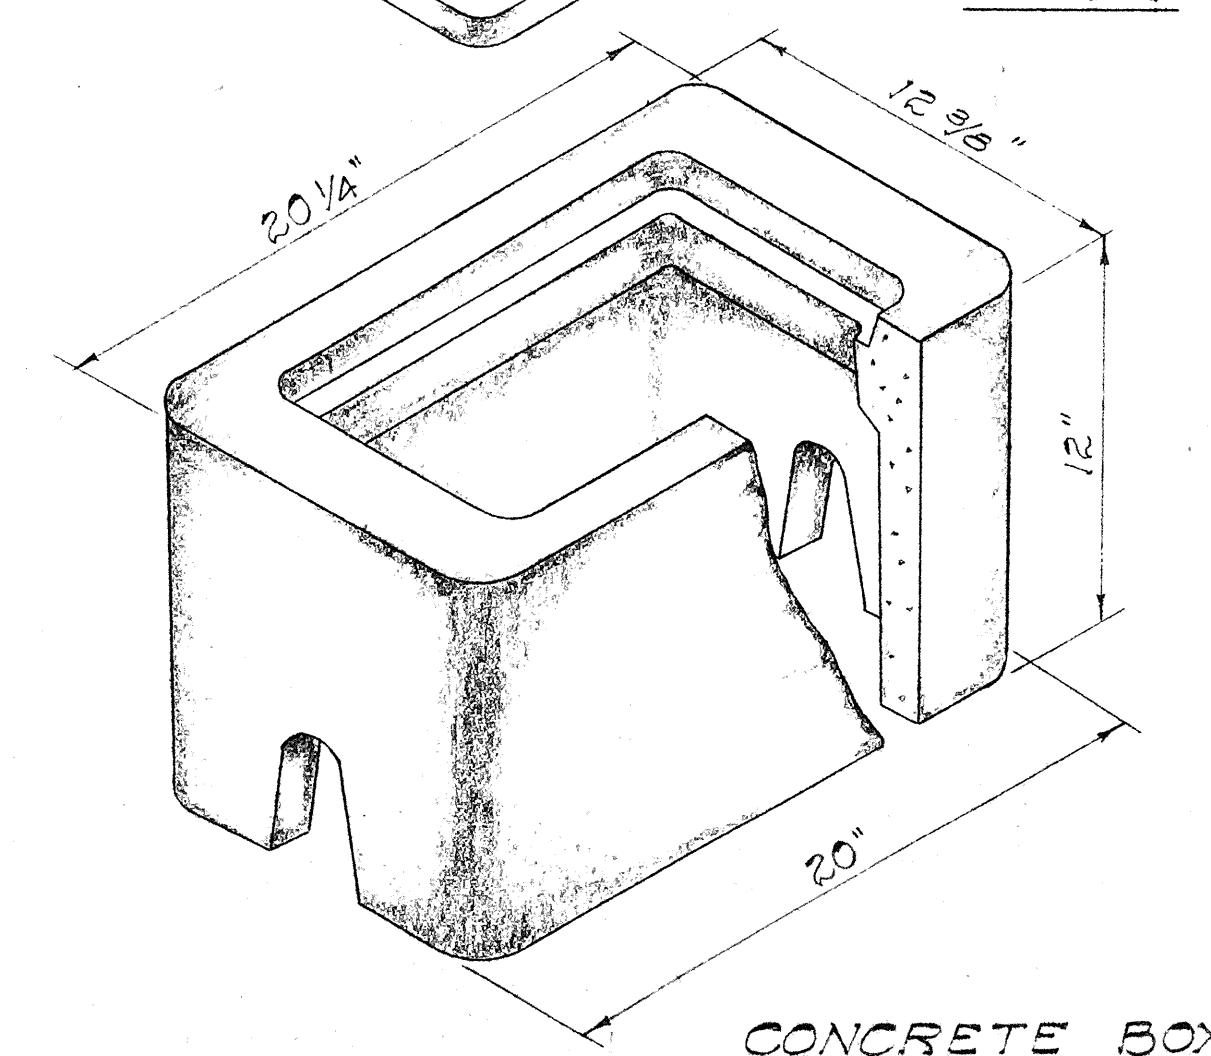

CONCRETE BOX

TYPE "B" METER BOX TYPE 436T

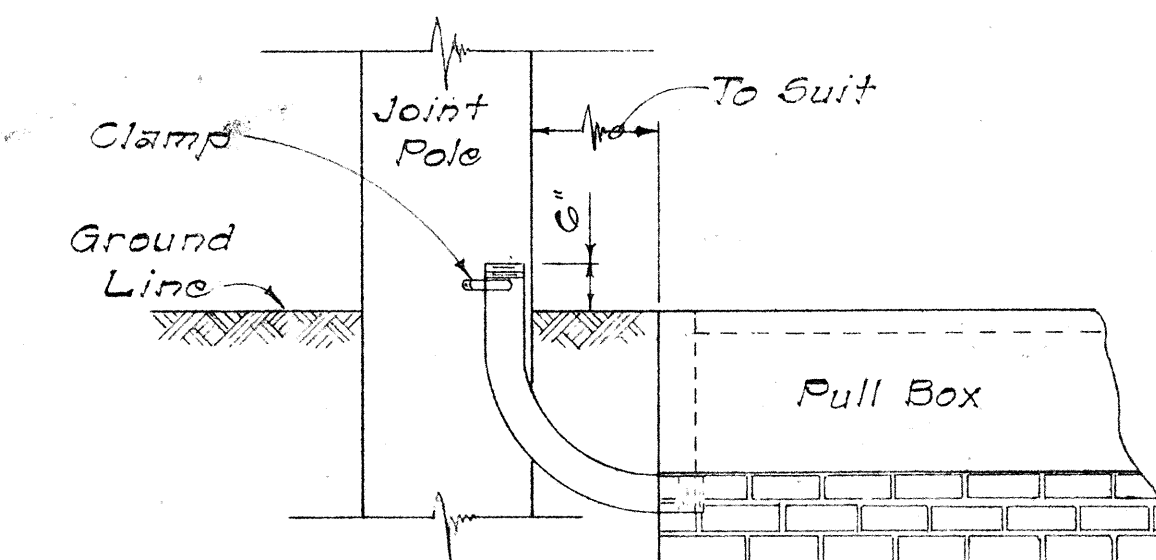

Field Side of Pole

TYPICAL 90° CONDUIT BEND TO POLE Not To Scale

APPROVED:
HAWAIIAN TELEPHONE CO. DATE

STATE OF HAWAII
DEPARTMENT OF TRANSPORTATION
HIGHWAYS DIVISION

STANDARD DETAILS
TELEPHONE PULL BOXES
Nos. 435T-B, 434T AND 436T

Scale: As Shown Date:

SHEET No. 12 OF 17 SHEETS



SURVEY PLOTTED BY	DATE
DESIGNED BY	
TRACED BY	
NOTE BOOK	
QUANTITIES BY	
CHECKED BY	

PLAN

SECTION "C-C"


INSTALLATION DETAIL OF PULL BOX No. 435T-B IN SIDEWALK AREAS

Scale: 1" = 1'-0"

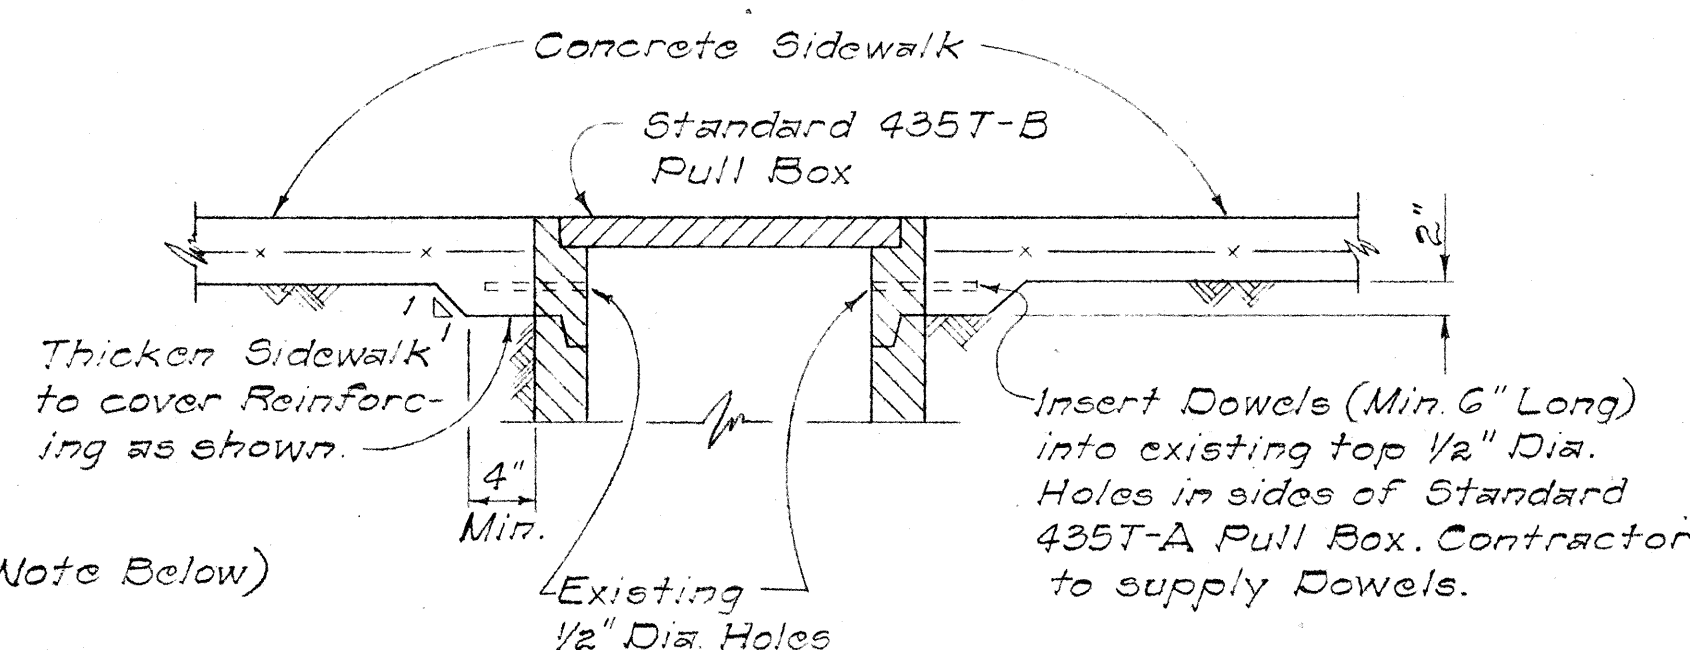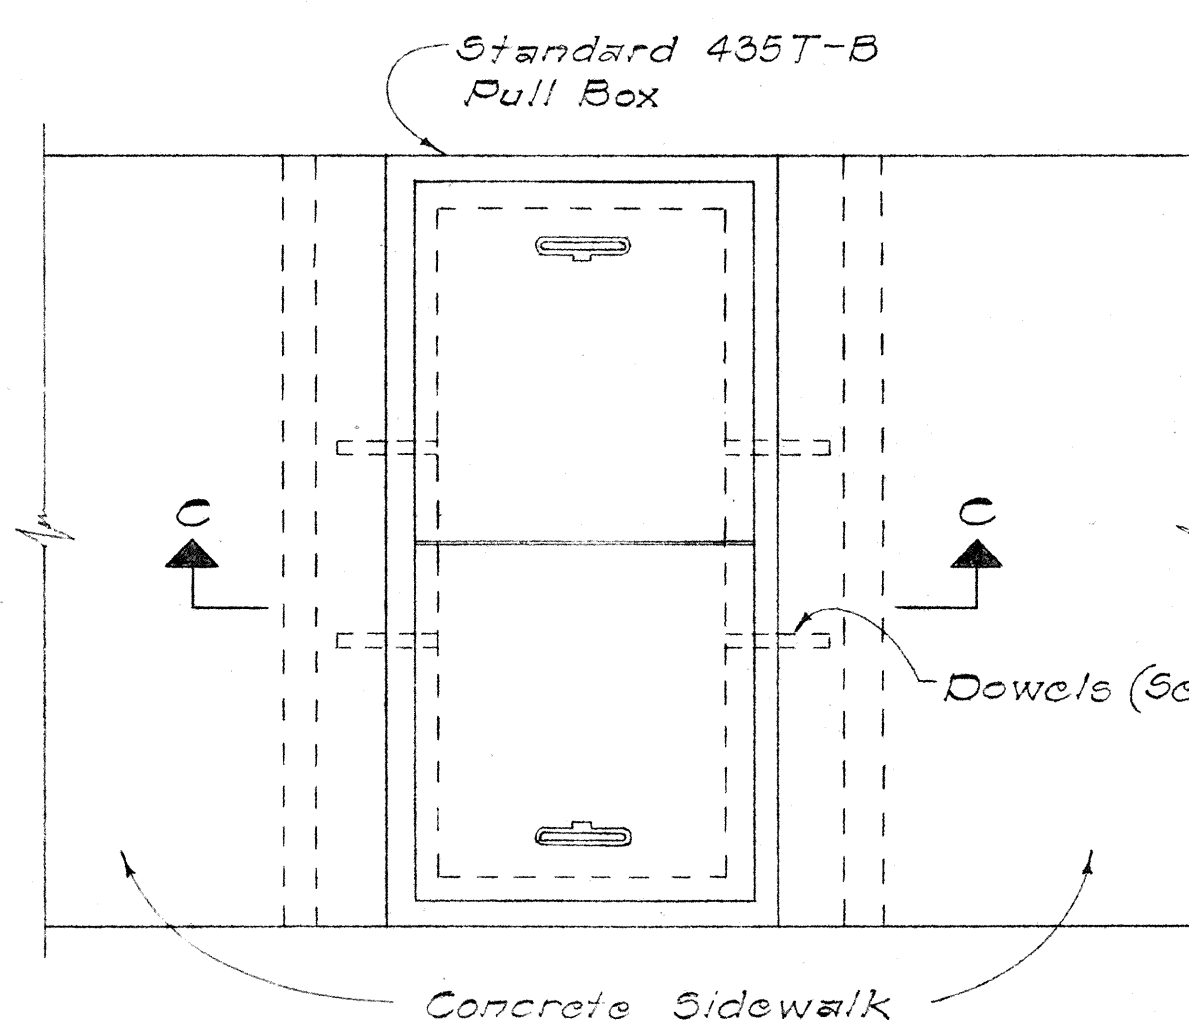

NOTE: Dowels shall be used only where the Sidewalk is as Wide or Narrower than the Pull Box.


FED. ROAD DIST. NO.	STATE	FED. AID PROJ. NO.	FISCAL YEAR	SHEET NO.	TOTAL SHEETS
HAWAII	HAWAII	I-HI-1(77)-3	1969	64	181

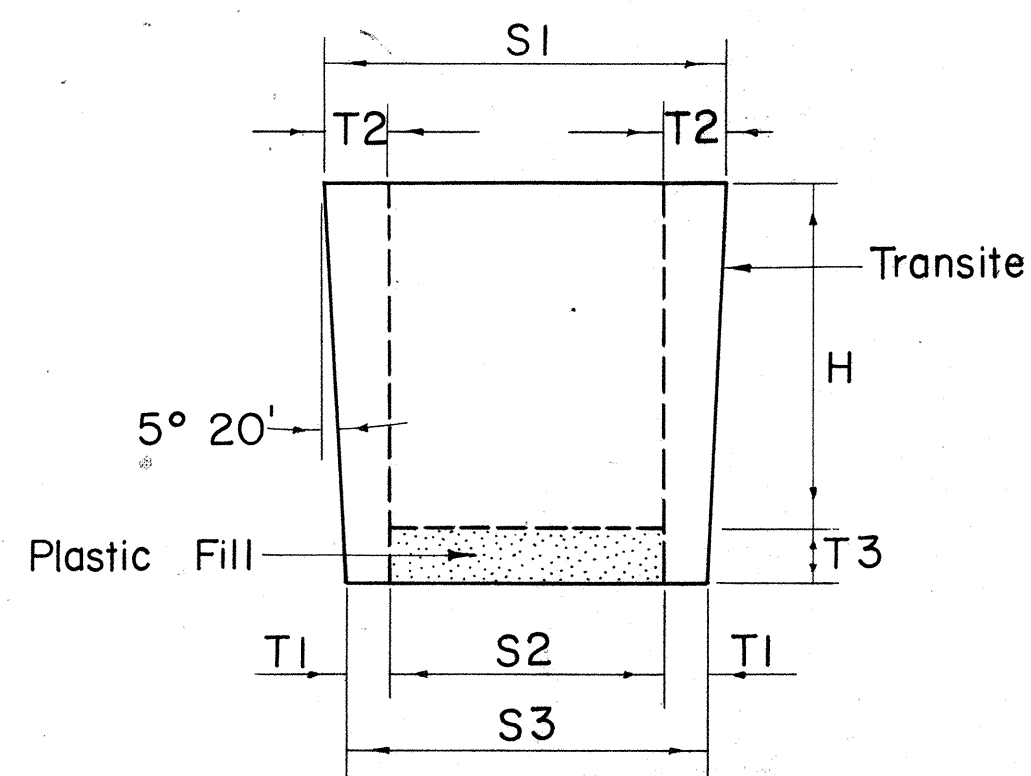

PLUGS FOR TRANSITE KORDUCTS

Not to Scale

SIZE	H	S1	S2	S3	T1	T2	T3
3"	4"	3 3/8"	2"	2 5/8"	5 1/16"	11 1/16"	3 3/4"
4"	4 1/2"	4 27/64"	2 3/4"	3 37/64"	13 3/32"	27 3/32"	3 3/4"
4 1/2"	4 1/2"	4 59/64"	3"	4 5/64"	35 3/32"	31 3/32"	3 3/4"
5"	4 1/2"	5 27/64"	3 1/2"	4 37/64"	35 3/32"	31 3/32"	3 3/4"

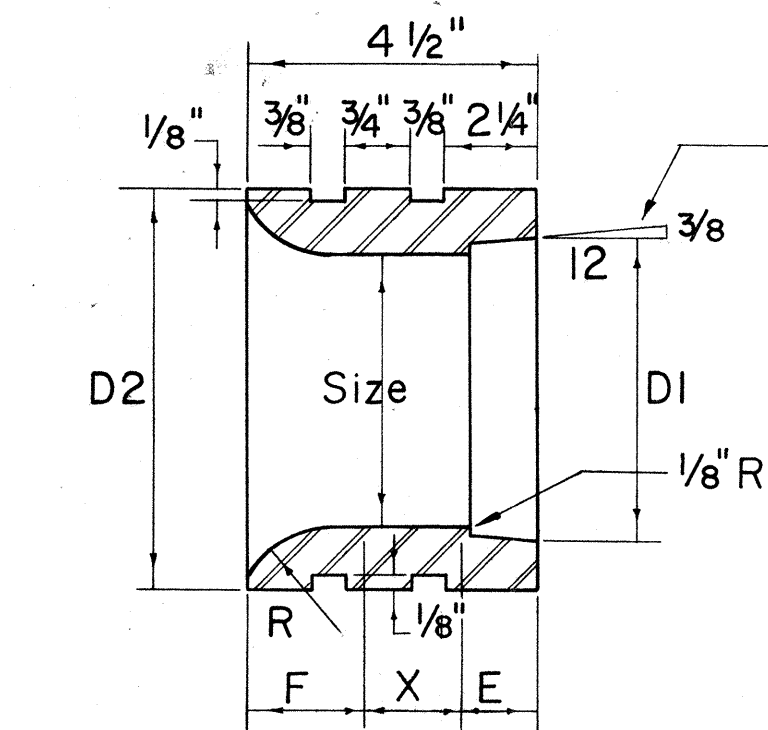


JUNIOR END BELLS

Not to Scale

SIZE	DI	D2	F	X	E	R
3"	3 25/64"	4 1/2"	1 11/32"	1 29/32"	1 1/4"	1 3/4"
4"	4 25/64"	5 3/4"	1 9/16"	1 9/16"	1 3/8"	2"
4 1/2"	4 57/64"	6 1/4"	1 9/16"	1 9/16"	1 3/8"	2"
5"	5 29/64"	7"	1 9/16"	1 7/16"	1 1/2"	2"

Note "X"

- Provide one set of Spacers
(a) 10 Ft. straight run for 4 Ducts high or less.
(b) 5 Ft. straight run for 5 Ducts high or more.

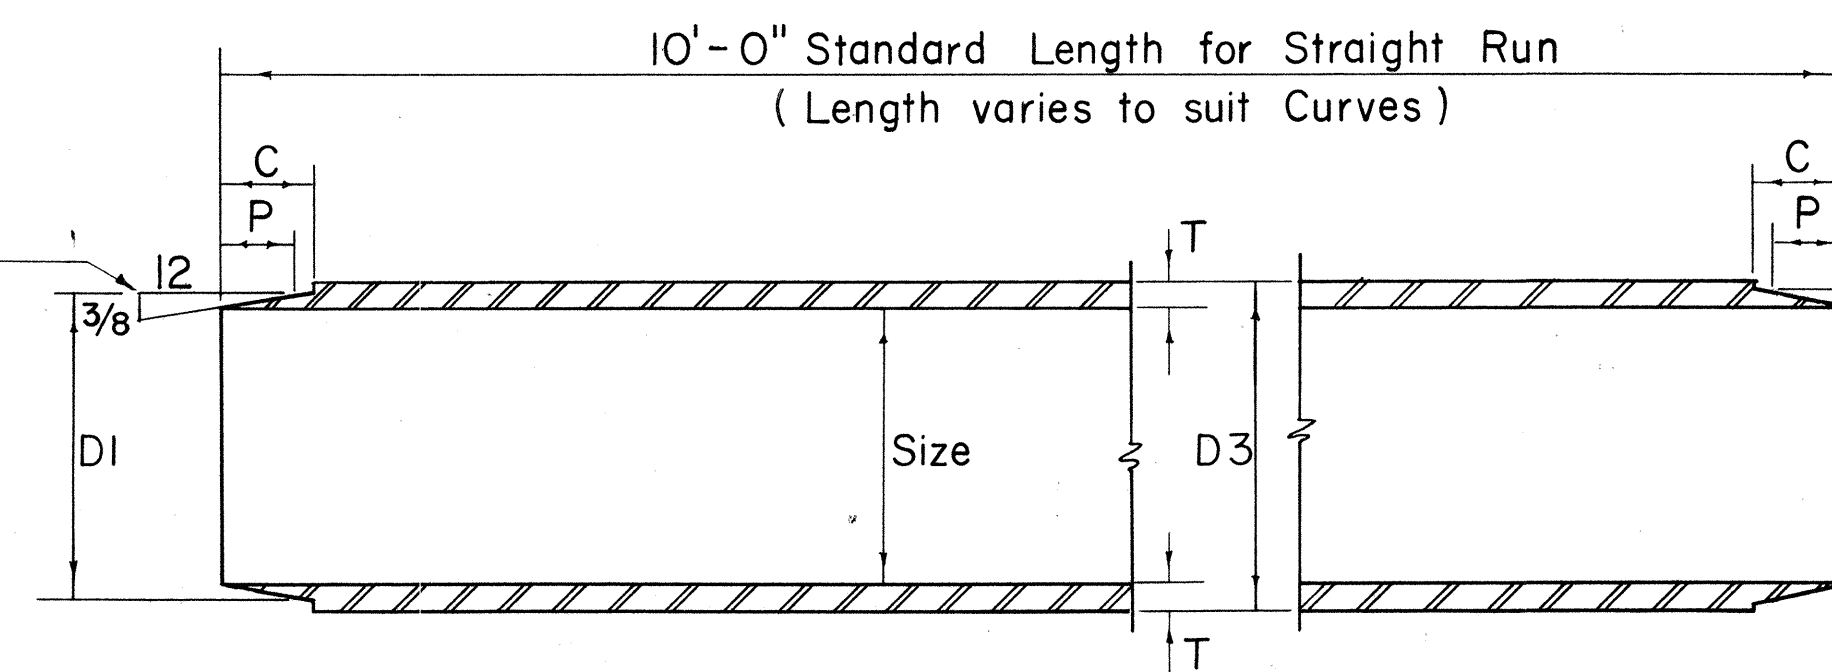

TRANSITE KORDUCTS


Not to Scale

SIZE	DI	D3	C	P	T
3"	3 25/64"	3 35/64"	1 1/8"	7 7/8"	17 1/64"
4"	4 25/64"	4 35/64"	1 1/4"	1"	17 1/64"
4 1/2"	4 57/64"	5 3/64"	1 1/4"	1"	17 1/64"
5"	5 29/64"	5 39/64"	1 25/64"	1 1/8"	19 1/64"

TAPERED COUPLINGS


Not to Scale

SIZE	DI	D2	L
3"	3 25/32"	4 11/64"	2 1/4"
4"	4 25/64"	5 3/16"	2 1/2"
4 1/2"	4 57/64"	5 49/64"	2 1/2"
5"	5 29/64"	6 21/64"	2 3/4"

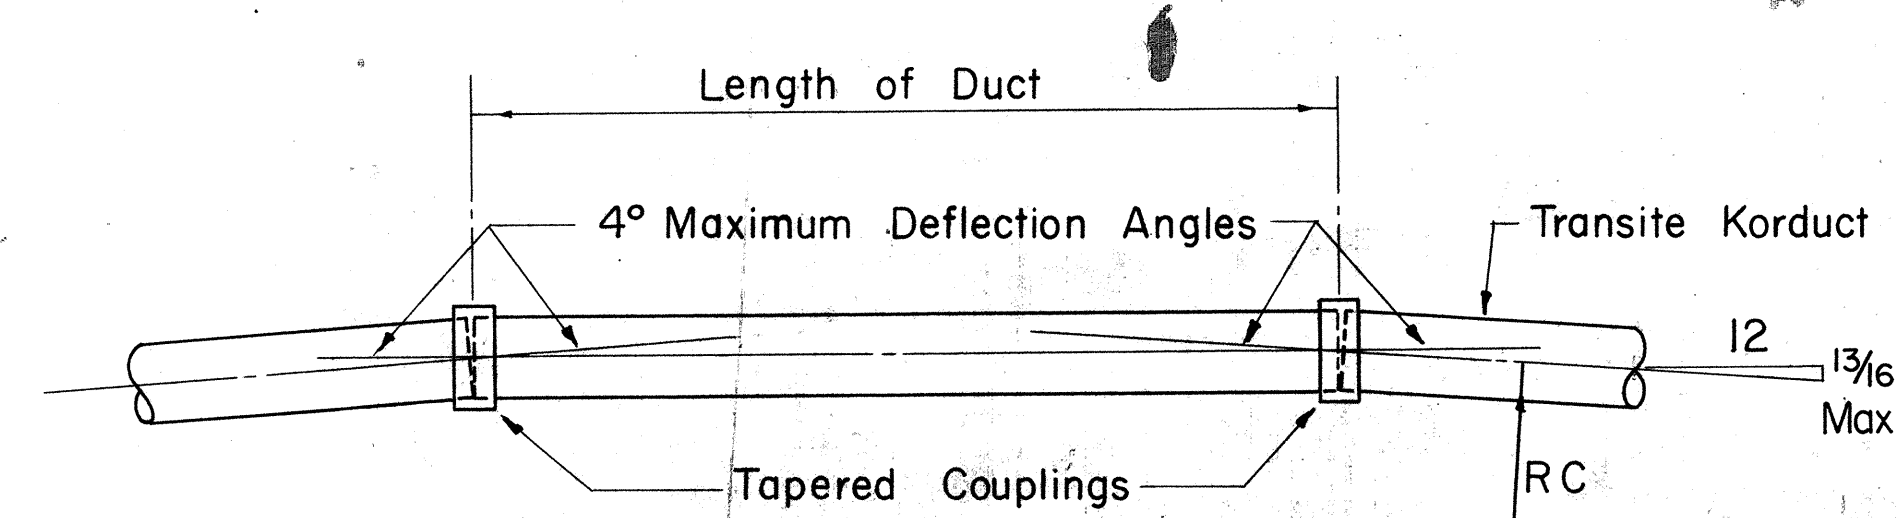

METHOD OF FORMING CURVES


Not to Scale

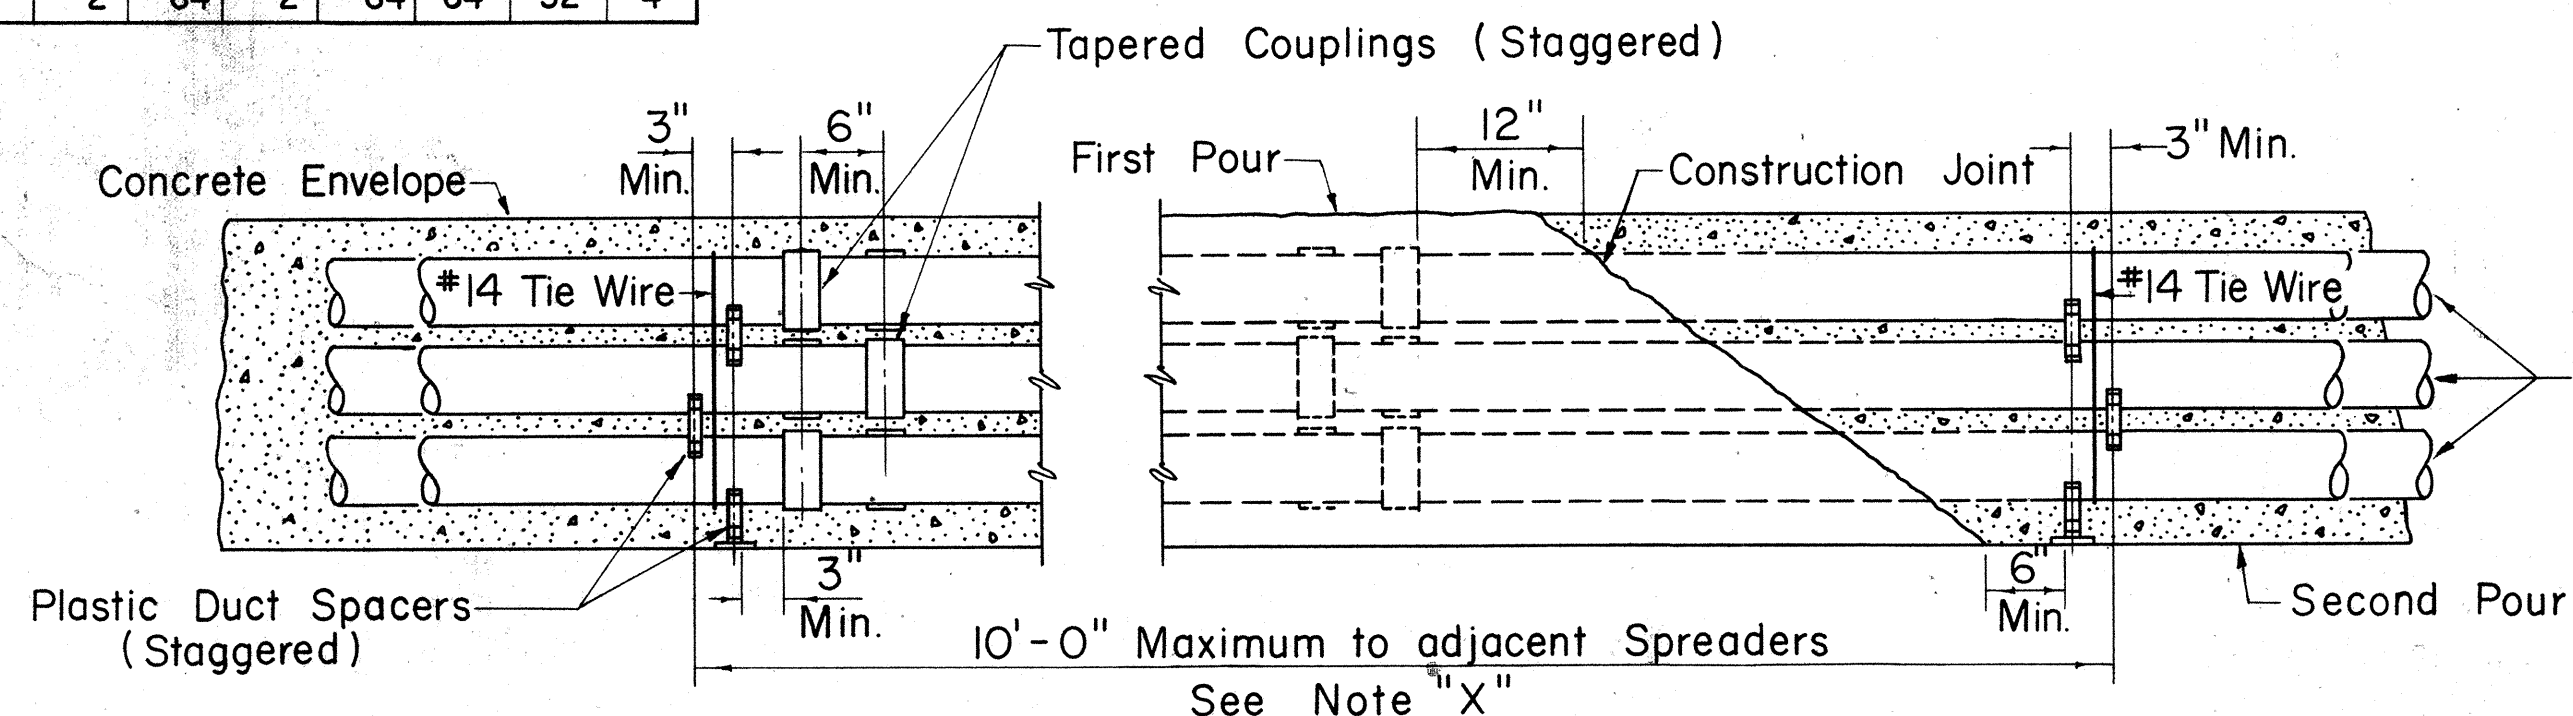

TYPICAL DUCT ENVELOPE ELEVATION

(6 WAY DUCT LINE SHOWN)


Not to Scale

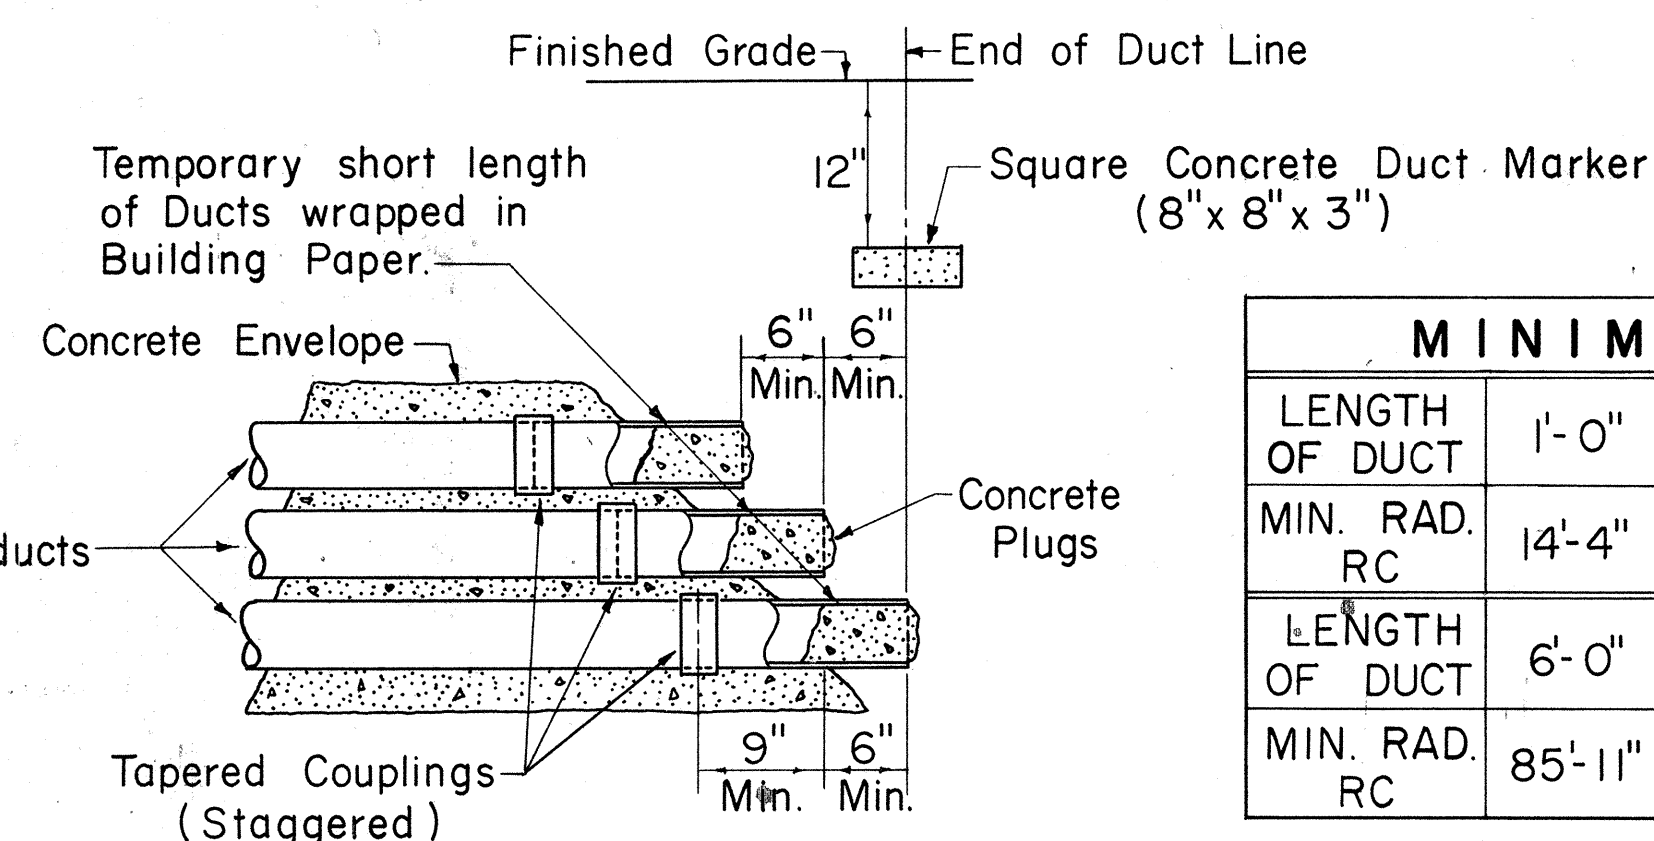

TYPICAL STUB OUT DETAIL


Not to Scale

	MINIMUM RADIUS TO FORM CURVES									
LENGTH OF DUCT	1'-0"	1'-6"	2'-0"	2'-6"	3'-0"	3'-6"	4'-0"	4'-6"	5'-0"	5'-6"
MIN. RAD. RC	14'-4"	21'-6"	28'-8"	35'-10"	42'-11"	50'-1"	57'-3"	64'-5"	71'-7"	78'-9"
LENGTH OF DUCT	6'-0"	6'-6"	7'-0"	7'-6"	8'-0"	8'-6"	9'-0"	9'-6"	10'-0"	
MIN. RAD. RC	85'-11"	93'-1"	100'-3"	107'-5"	114'-7"	121'-8"	128'-10"	136'-0"	143'-2"	

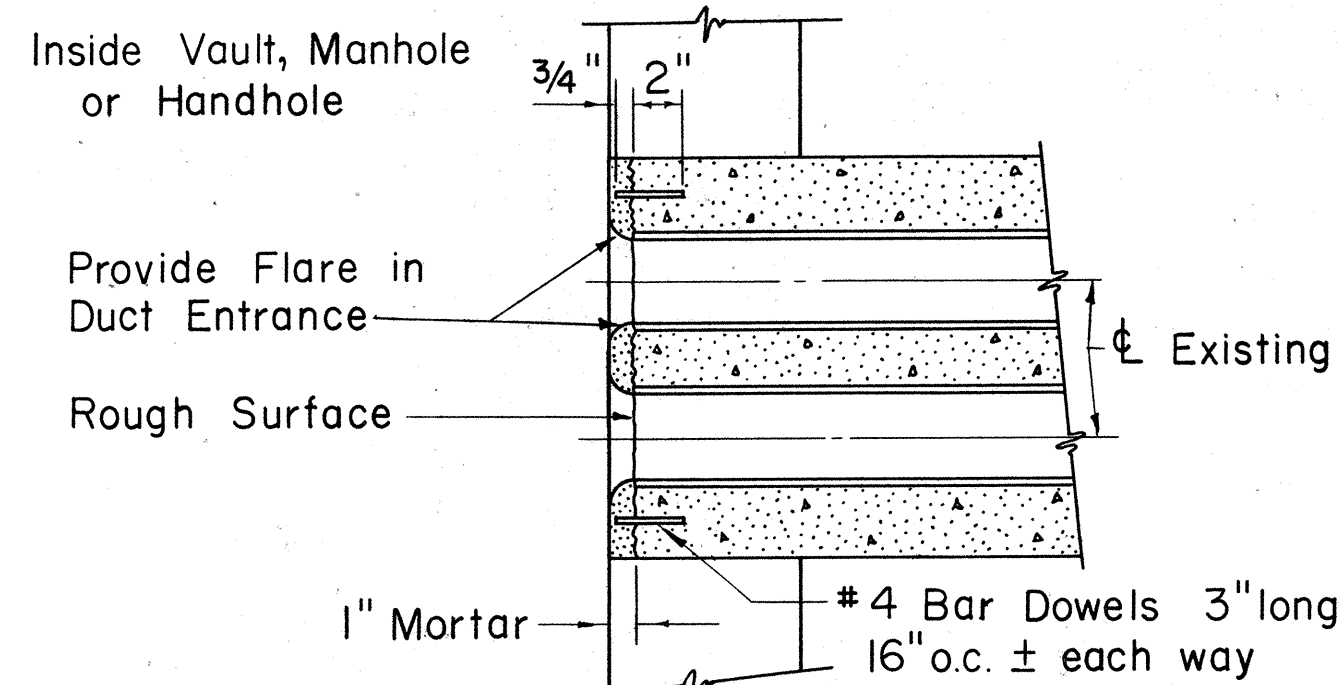

DUCT LINE ENTRANCE AT EXISTING DUCT LINE

Scale: 1 1/2" = 1'-0"

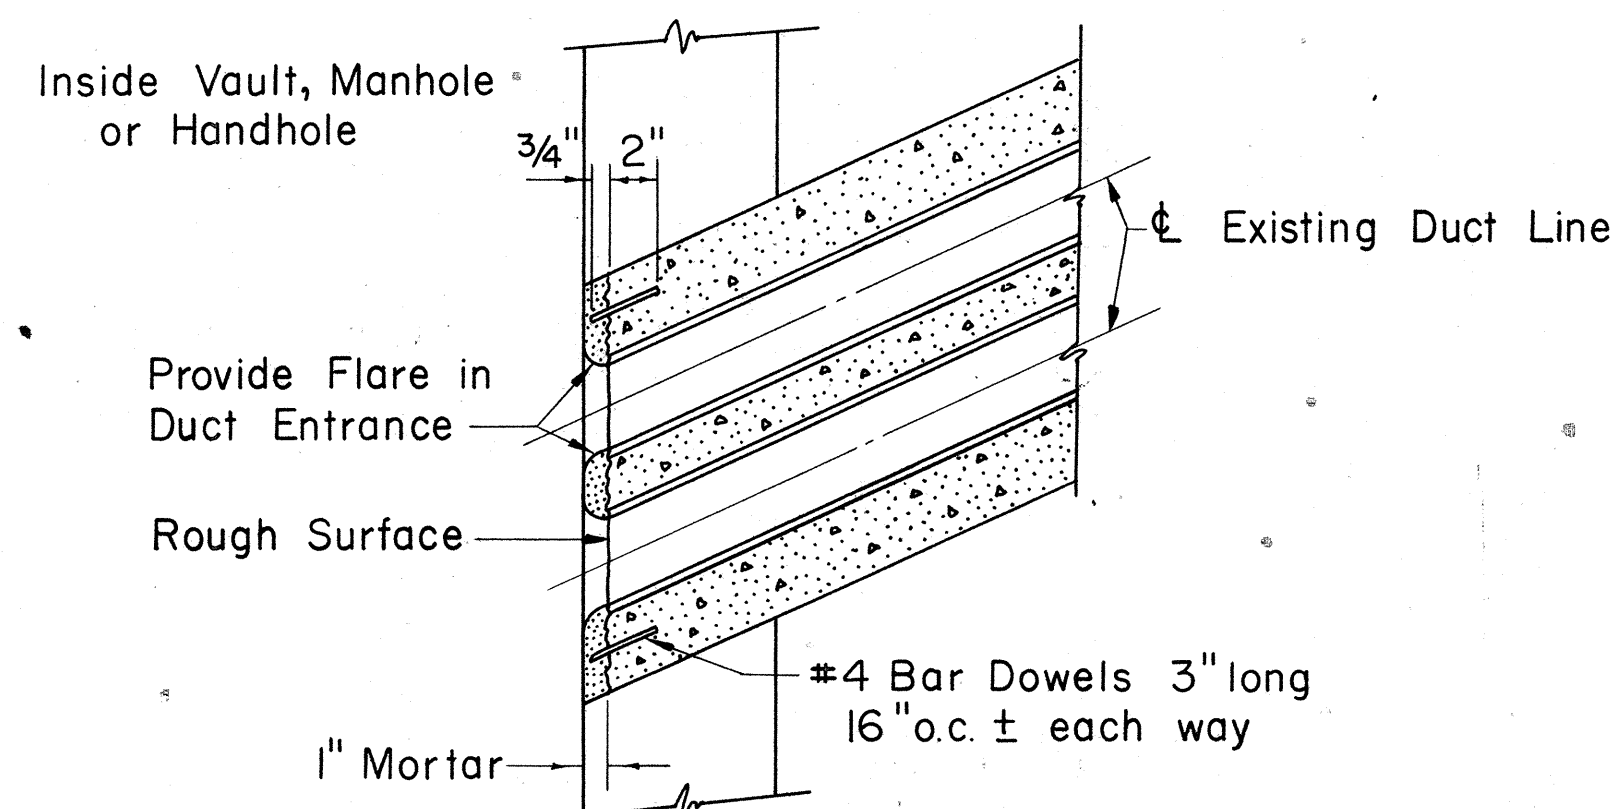

DUCT LINE DIAGONAL ENTRANCE

Scale: 1 1/2" = 1'-0"




HECo., Inc. Drawing Number	
18585	SHEET No. 2 OF 2 SHEETS
STATE OF HAWAII DEPARTMENT OF TRANSPORTATION HIGHWAYS DIVISION	
STANDARD DETAILS	
CONSTRUCTION STANDARDS TRANSITE KORDUCTS UNDERGROUND DUCT LINES	

Scales: As Noted

Date

SHEET NO. 14 OF 17 SHEETS




FED. ROAD DIST. NO.	STATE	FED. AID PROJ. NO.	FISCAL YEAR	SHEET NO.	TOTAL SHEETS
HAWAII	HAWAII	1-HI-(75)-8	1969	65	181

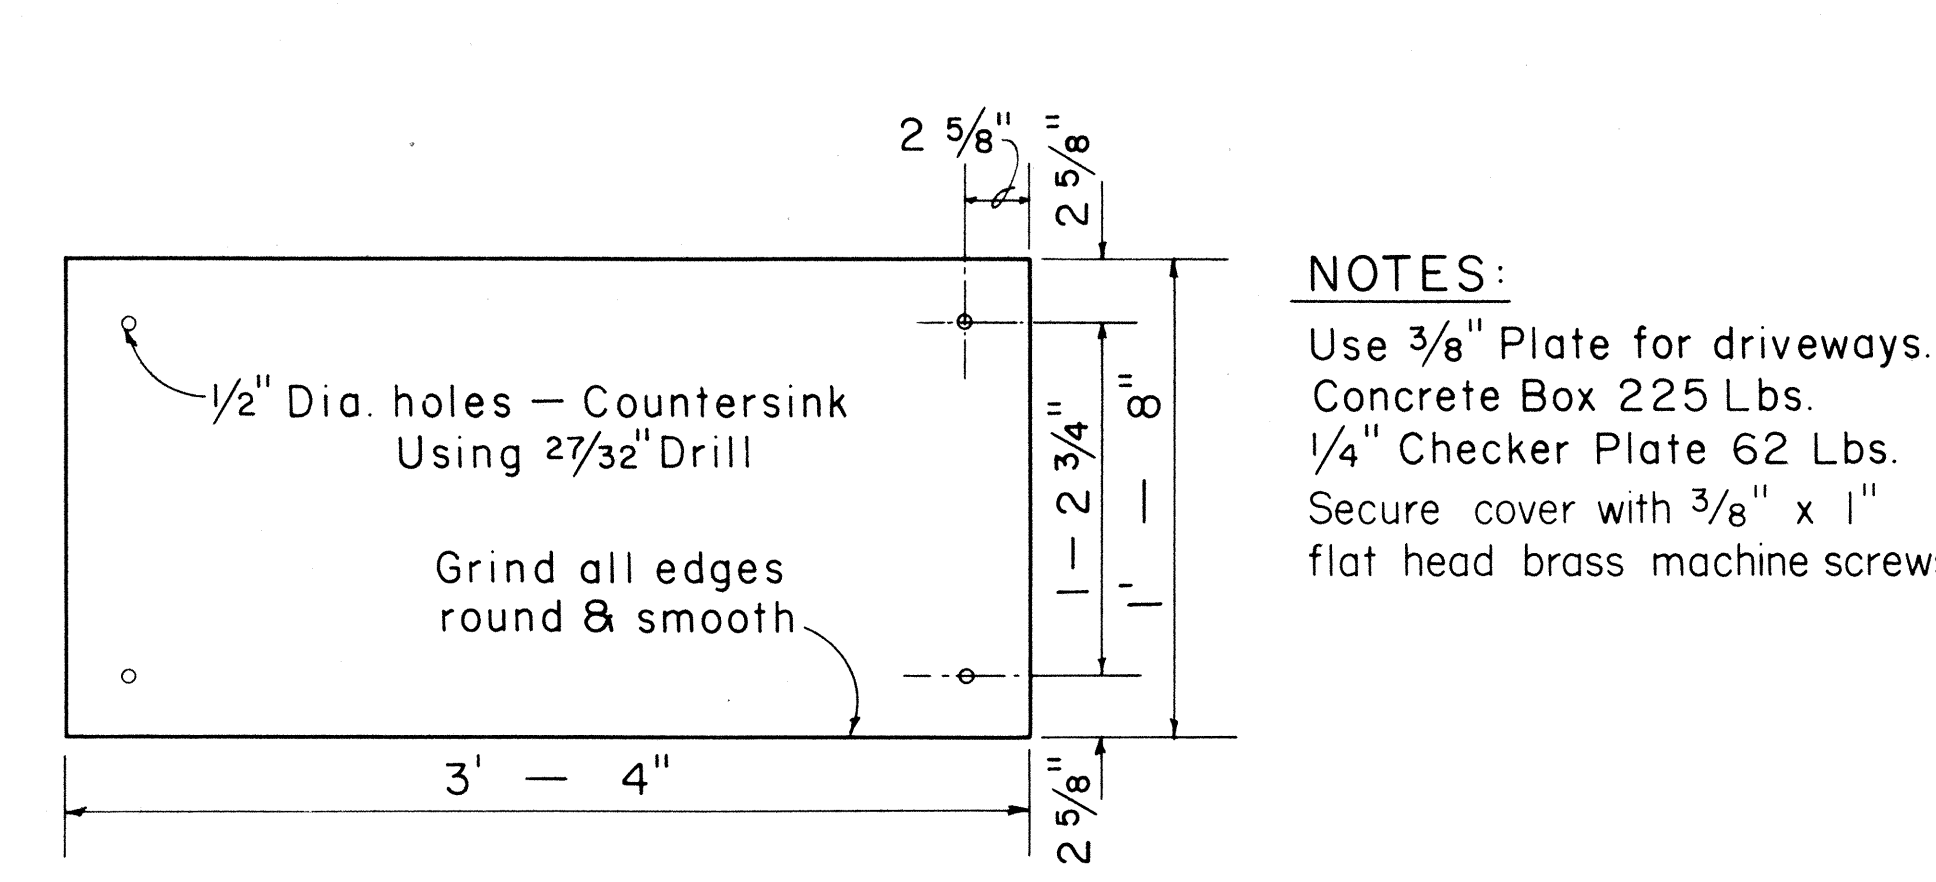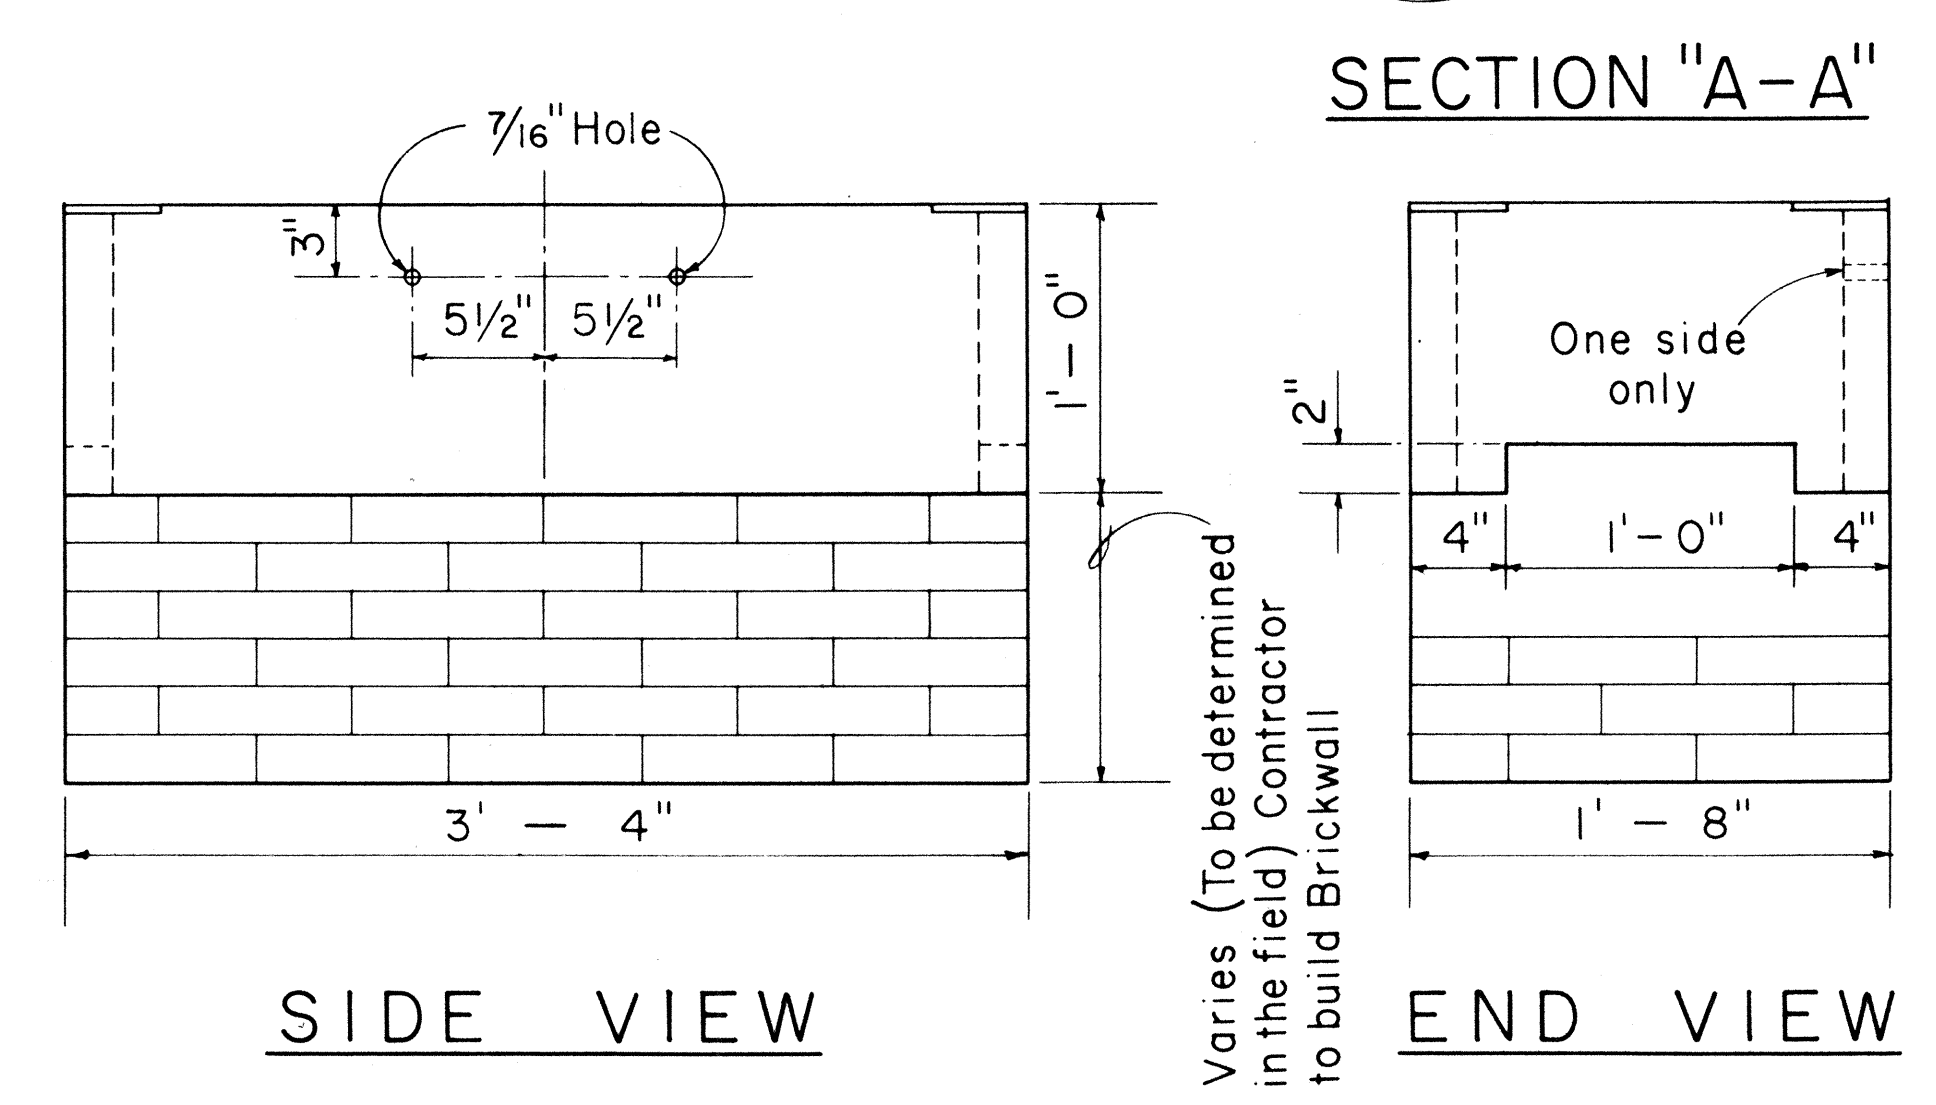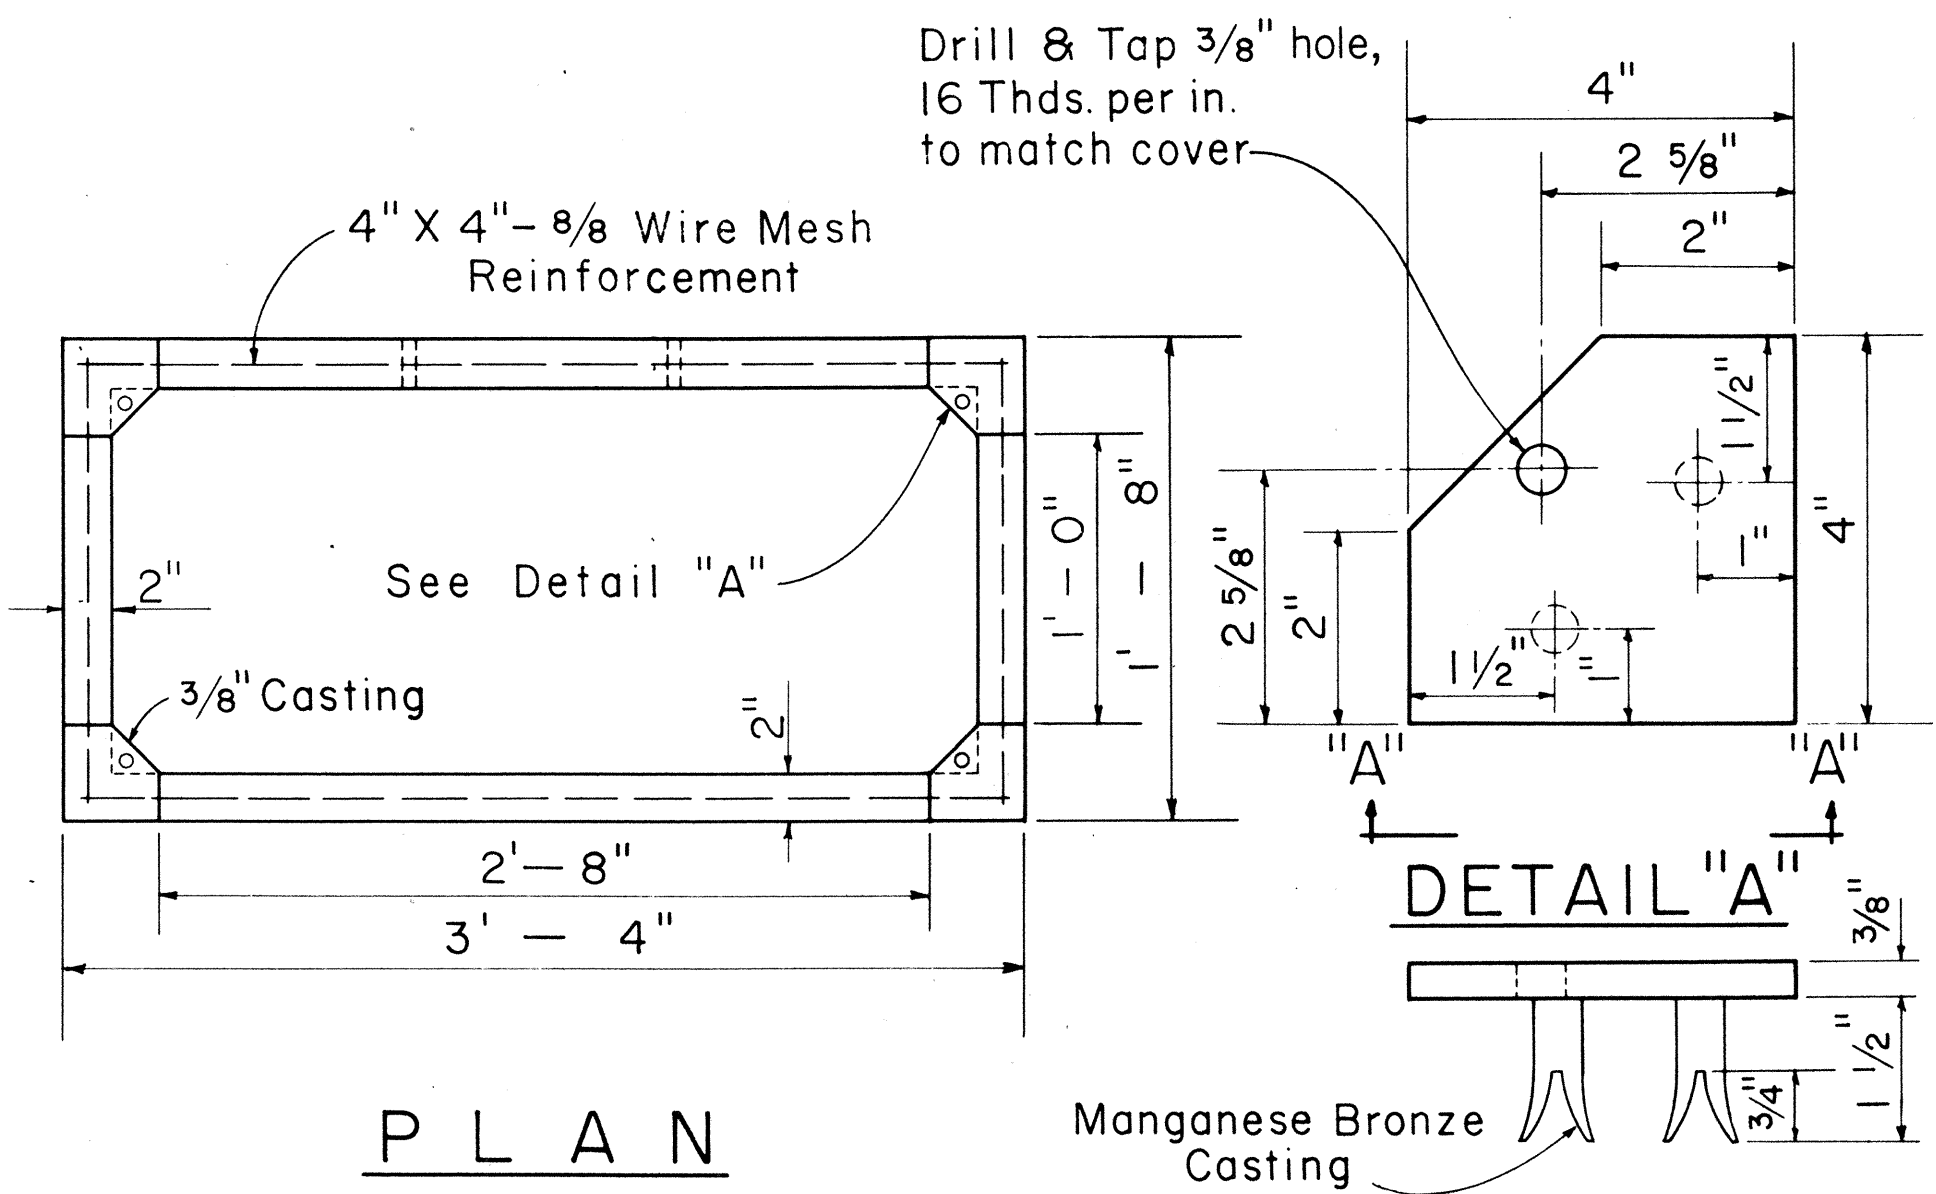

1/4" CHECKER PLATE COVER
(Hot dip galvanize checkered plate after drilling, countersinking, and grinding edge)

1'-4" X 3'-0" CONCRETE SERVICE BOX
Scale: 1 1/2" = 1' - 0"

011250

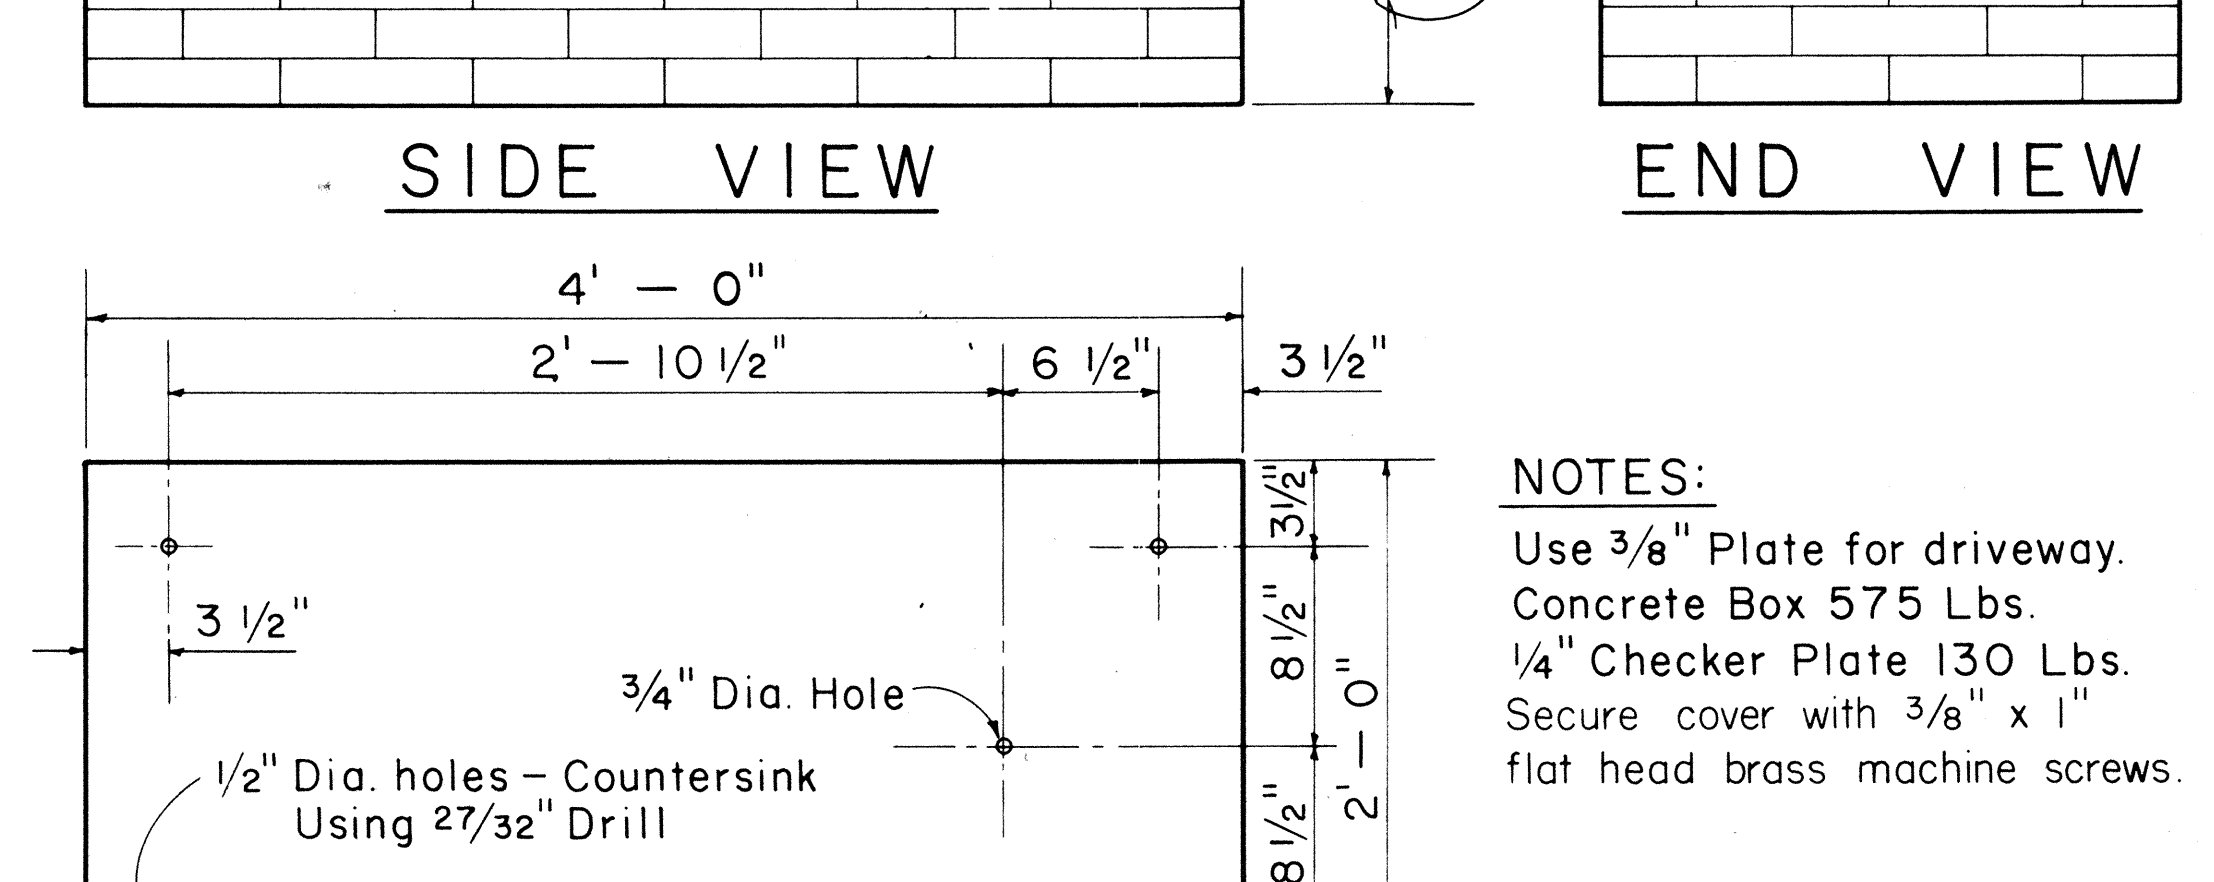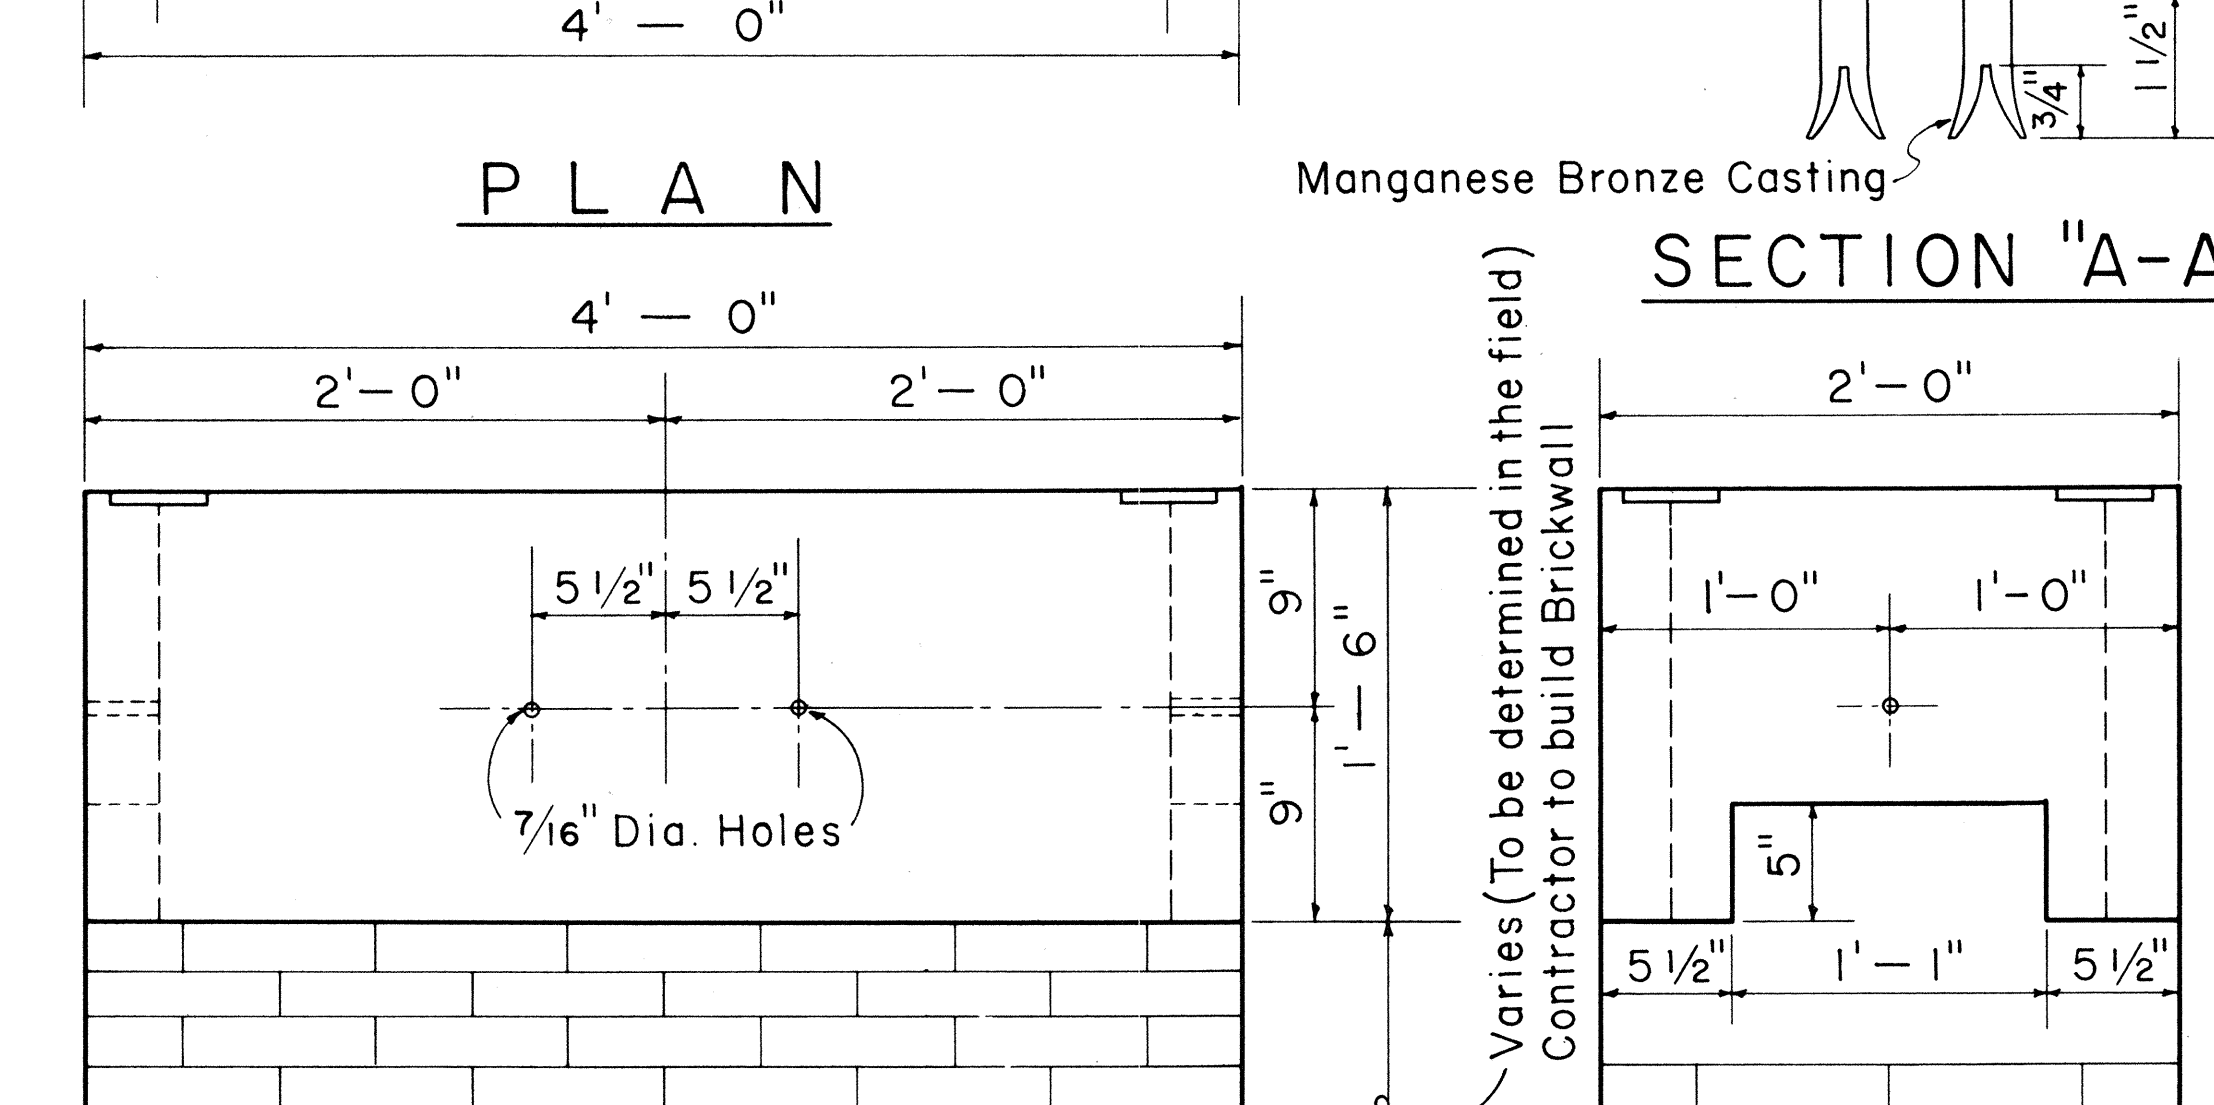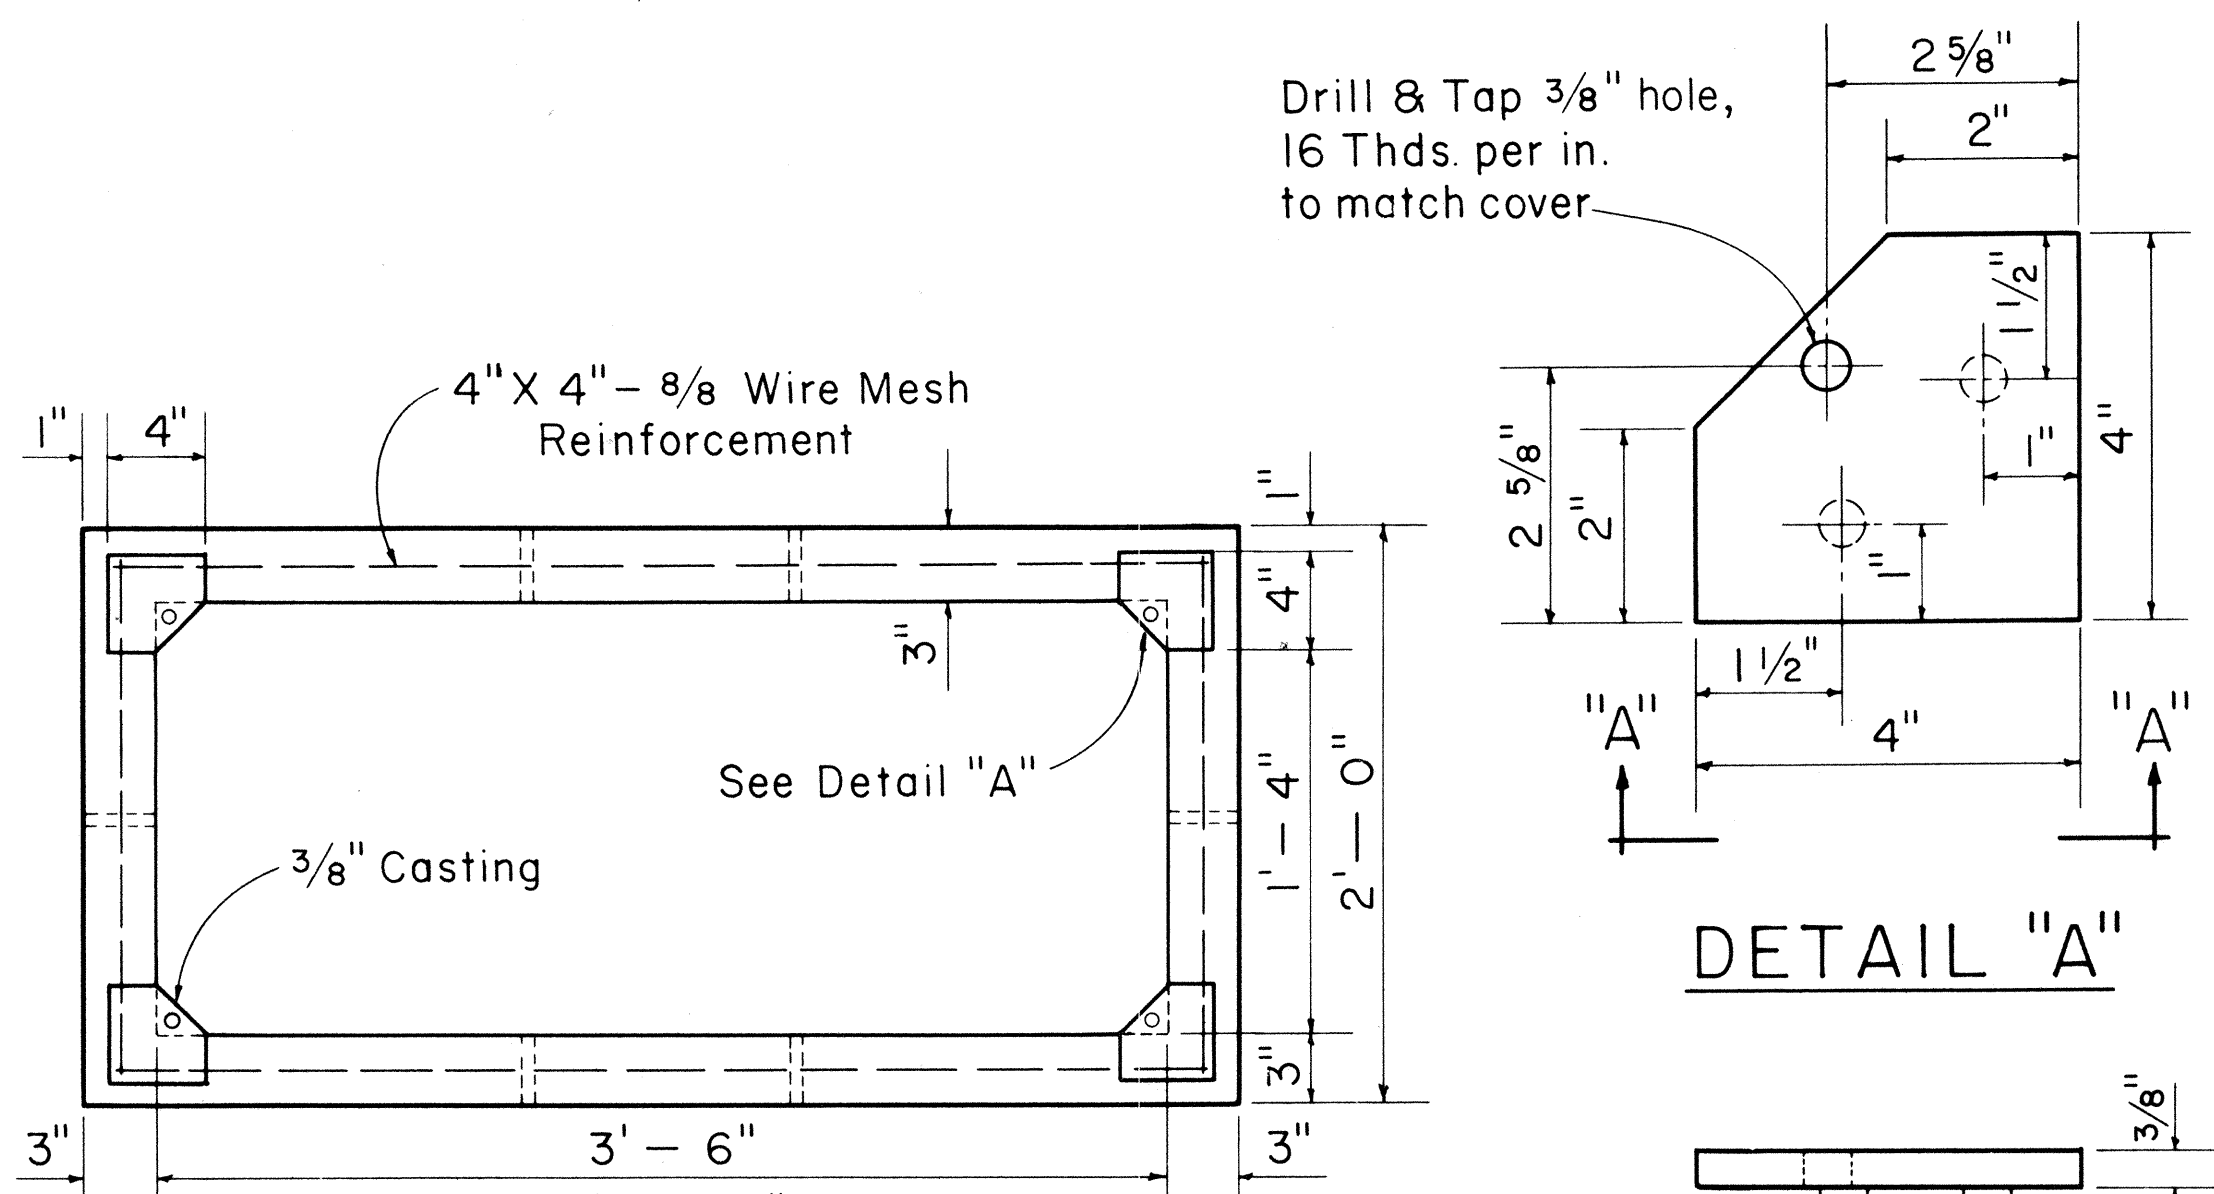

1/4" CHECKER PLATE COVER
(Hot dip galvanize checkered plate after drilling, countersinking, and grinding edge)

1'-6" X 3'-6" CONCRETE SERVICE BOX
Scale: 1 1/2" = 1' - 0"

011255

CREOSOTED DOUGLAS FIR & YELLOW PINE POLE DATA									
LENGTH IN FEET	CLASS	APPROX. MINIMUM DIMENSIONS (INCHES)				AVERAGE WEIGHT (LBS.)	POLE SETTING DEPTH (FT.)		BREAKING LOAD 2'-0" BELOW TOP OF POLE (LBS.)
		AT TOP		6' FROM BUTT		DOUGLAS FIR	IN SOIL	IN ROCK	
		DIA.	CIR.	DIA.	CIR.				
25	5	6.04	19	8.26	26	525	4.5	3	1900
30	3	7.32	23	10.32	32.5	810	5	3.5	3000
	5	6.04	19	8.90	28	600	5	3.5	1900
35	2	7.96	25	12.23	37.5	1260	5	3.5	3700
	5	6.04	19	9.55	30	770	5	3.5	1900
40	3	7.32	23	11.77	37	1320	5.5	3.5	3000
45	2	7.96	25	13.20	41.5	1845	6	4	3700
	3	7.32	23	12.25	38.5	1575	6	4	3000
50	2	7.96	25	13.70	43	2150	6.5	4	3700
	3	7.32	23	12.70	40	1850	6.5	4	3000
55	1	8.59	27	15.11	47.5	2860	7	4.5	4500
	2	7.96	25	14.15	44.5	2475	7	4.5	3700
	3	7.32	23	13.20	41.5	2145	7	4.5	3000
60	1	8.59	27	15.75	49.5	3360	7	4.5	4500
	2	7.96	25	14.62	46	2820	7	4.5	3700
65	1	8.59	27	16.20	51	3835	7.5	5	4500
	2	7.96	25	15.11	47.5	3250	7.5	5	3700
70	1	8.59	27	16.70	52.5	4340	7.5	5	4500
	2	7.96	25	15.60	49	3640	7.5	5	3700
75	1	8.59	27	17.20	54	4800	8	5.5	4500
	2	7.96	25	16.05	50.5	4050	8	5.5	3700
80	1	8.59	27	17.50	55	5240	8	6	4500
	2	7.96	25	16.40	51.5	4400	8	6	3700
85	1	8.59	27	18.00	56.5	5780	8.5	6.5	4500
	2	7.96	25	16.88	53	4930	8.5	6.5	3700
90	1	8.59	27	18.30	57.5	6300	8.5	6.5	4500
	2	7.96	25	17.20	54	5400	8.5	6.5	3700

NOTE:
The ultimate fiber stress for creosoted Southern Yellow Pine & Douglas Fir is 7,400 Lbs. per square inch.

Weights are for untreated poles. Add 5% as estimate of added weight of creosote treatment.




REFERENCES:
American Standards Association O5.4-1941, O5.6-1945.
Standard Handbook for Electrical Engineers, Eighth Edition
H. E. Co. Specification for Poles.

WOOD POLE DATA

STATE OF HAWAII
DEPARTMENT OF TRANSPORTATION
HIGHWAYS DIVISION
STANDARD DETAILS
H.E. Co. AND H.T. Co.
SERVICE BOX DETAILS
AND WOOD POLE DATA
Scales: As Noted
Date




SHEET NO. 15 OF 17 SHEETS

FED. ROAD DIST. NO.	STATE	FED. AID PROJ. NO.	FISCAL YEAR	SHEET NO.	TOTAL SHEETS
HAWAII	HAWAII	1-11-15	1969	66	181


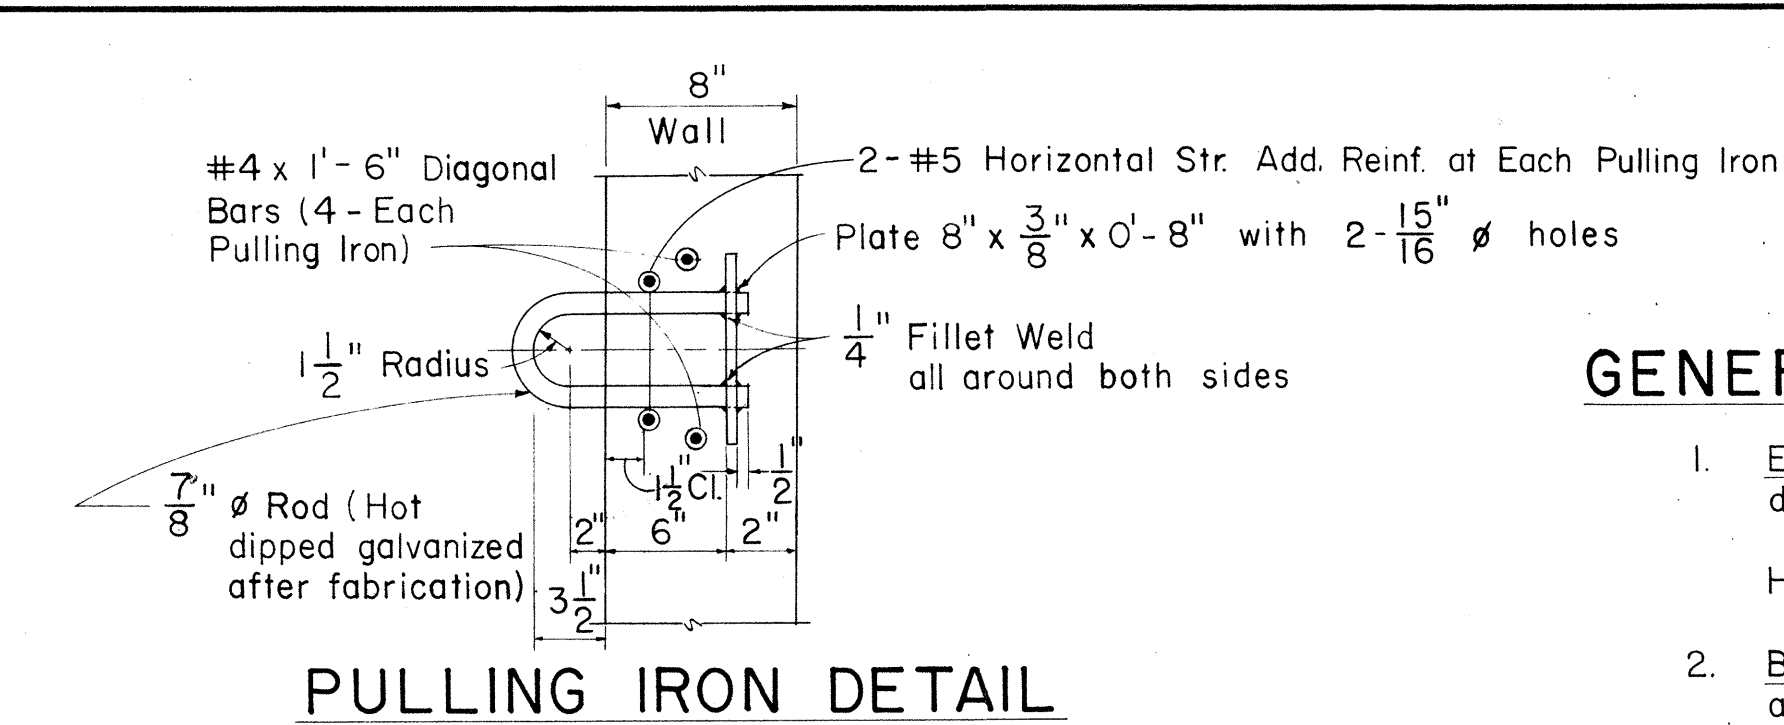
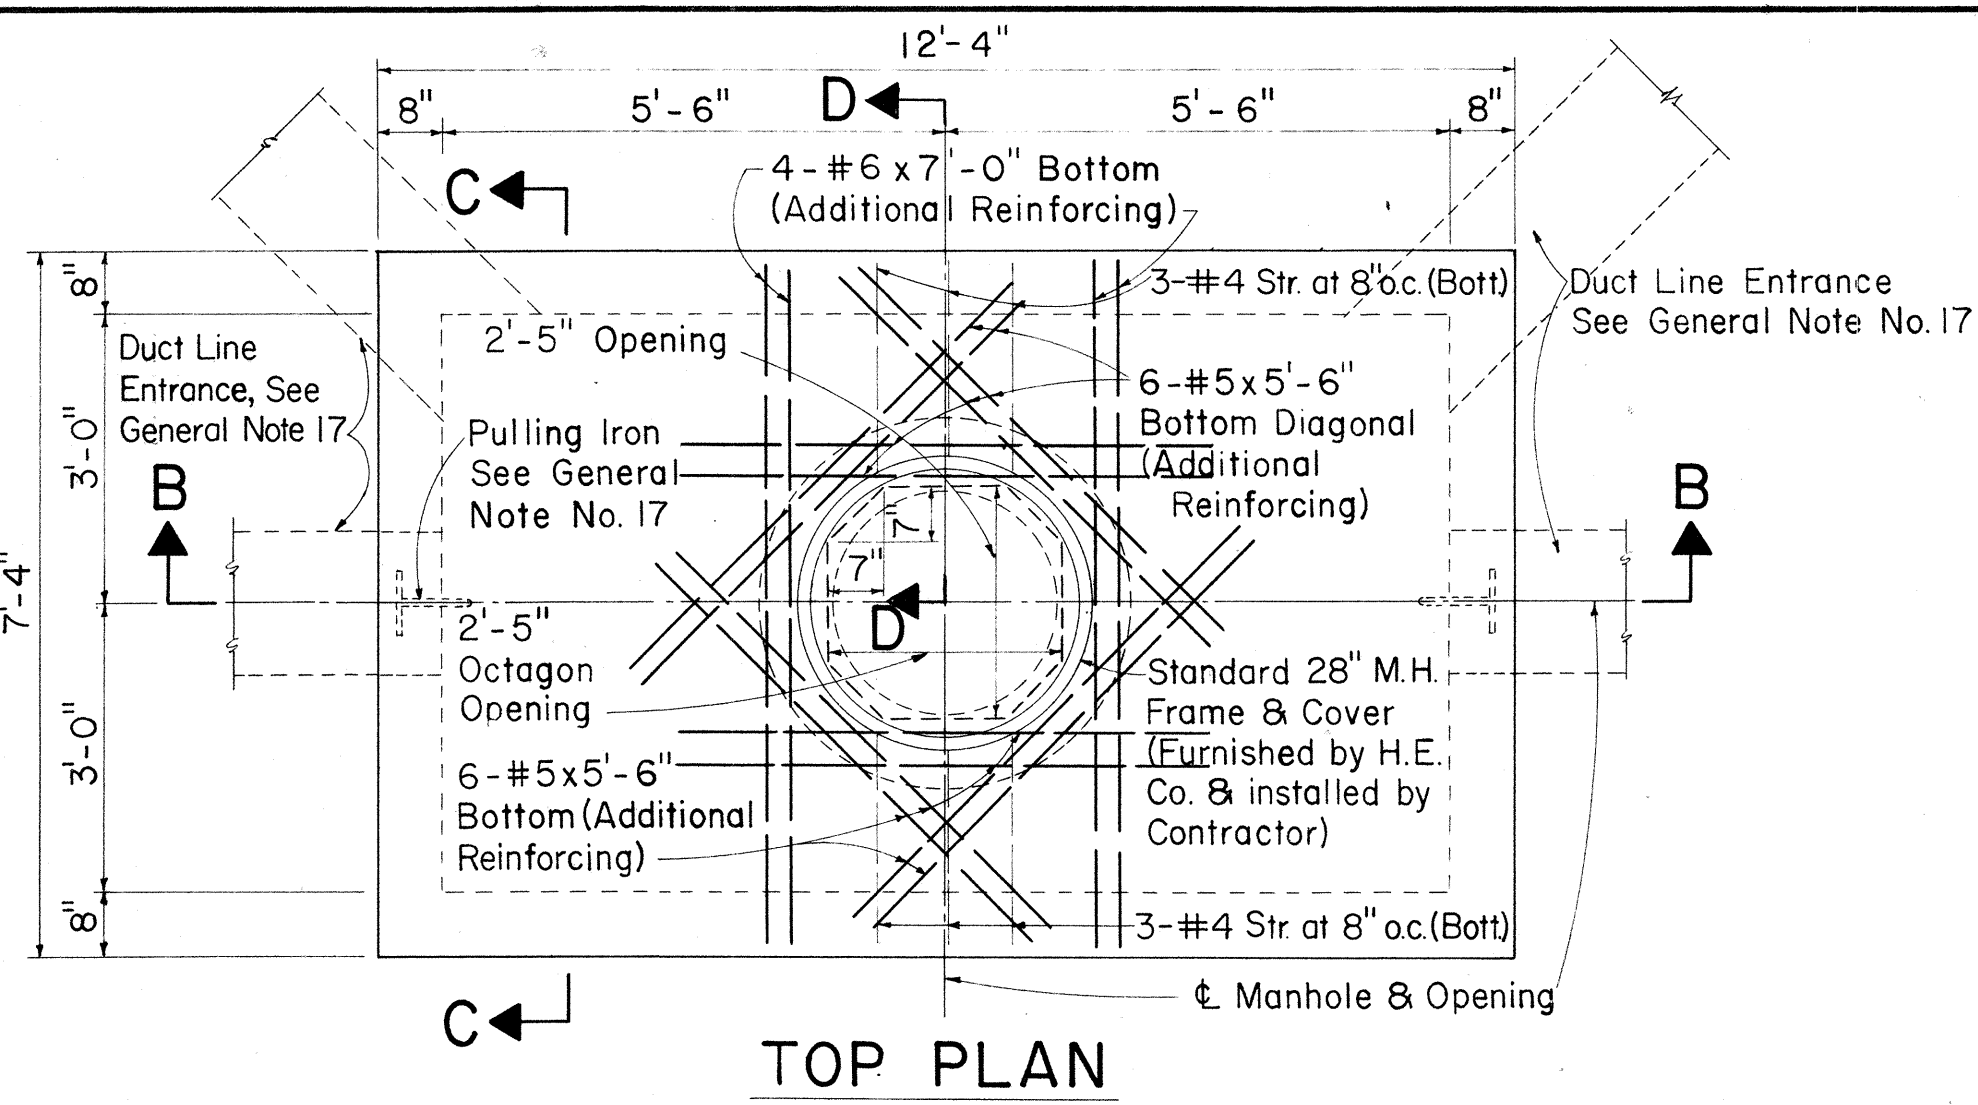
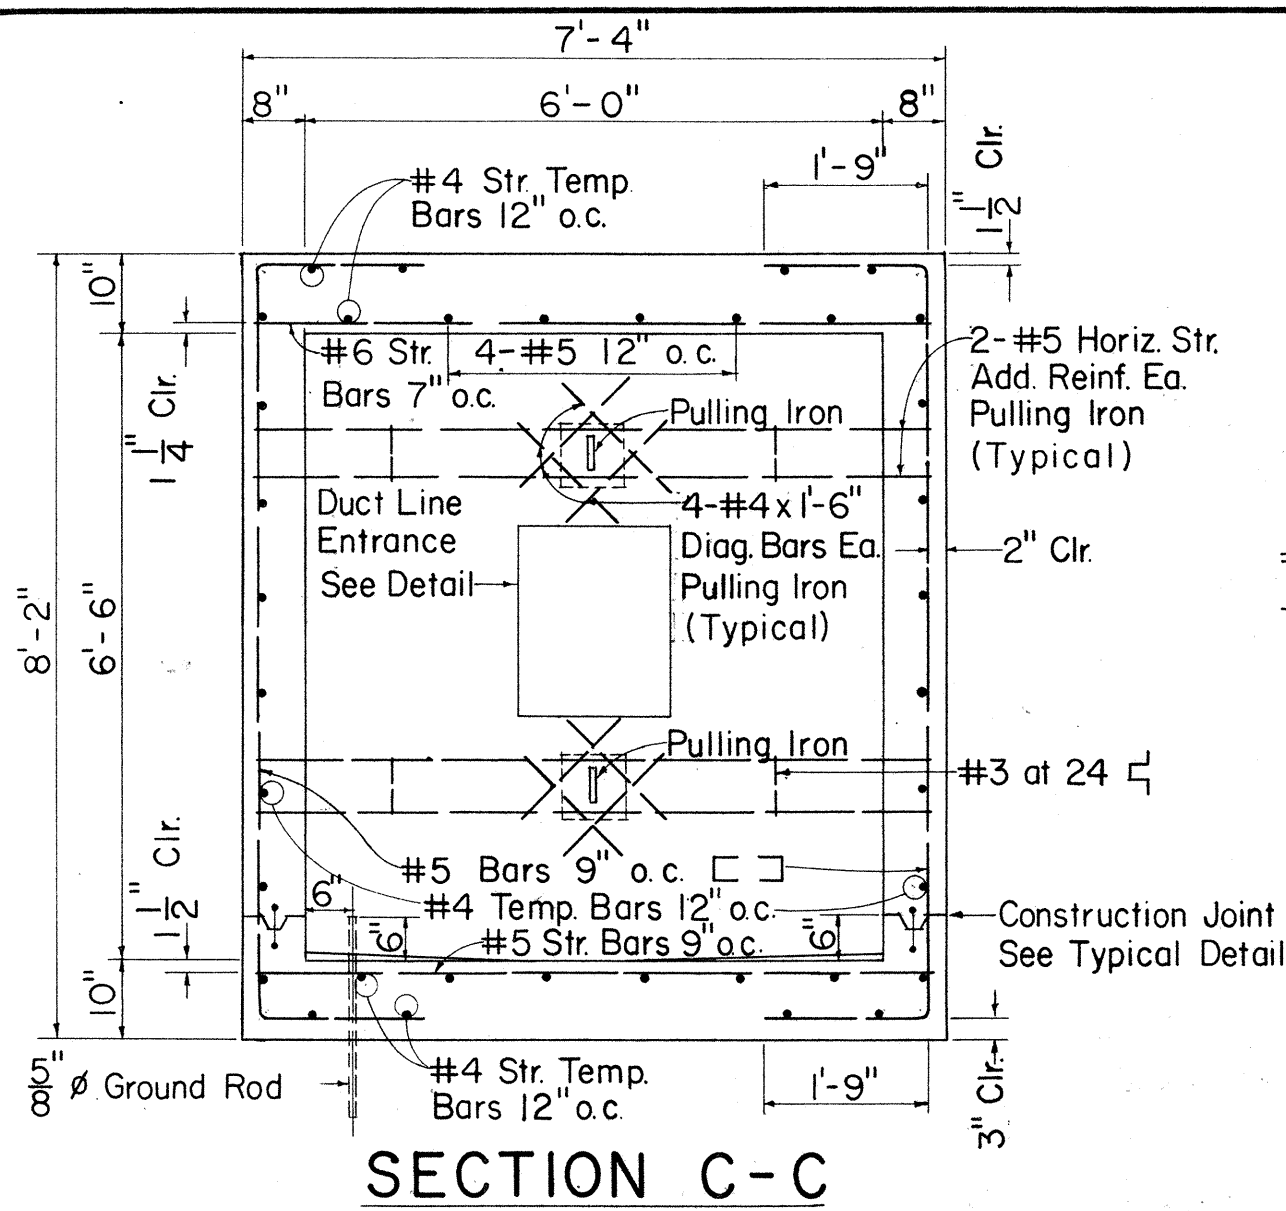


GENERAL NOTES

- EXCAVATION**: Excavate for manhole to accurate alignment, grades and dimensions as shown on drawings. All excavation must be approved by Engineering Dept. H.E.Co. before any concrete is poured. All excess cut shall be backfilled with concrete or rocks.
- BACKFILL**: Remove all debris before backfilling. Backfill in accordance with latest specifications of Division of Highways, State of Hawaii.
- All work to be done in dry.
- Concrete shall be Class A-1 conforming to the requirements of Section 47 of the Special Provisions.
- MIXING**: Ready-Mixed A.S.T.M. C-94-47.
- REINFORCING**: Round deformed bars (clean and new).
- SPLICE**: Lap 30 bar diameters unless otherwise shown.
- CURING**: Keep concrete moist at least 7 days after pouring. (By approved method).
- FINISH**: All surfaces smooth and free from defects. Top of manhole - wood floated. Manhole floor - steel troweled. Inside walls and ceiling - cement washed.
- Install all inserts, including pulling irons, ground rods, etc, before pouring concrete.
- POURING**: Notify the H.E.Co. Contracting and Inspection Division, 24 hours before pouring any concrete. All concrete pouring shall be done in the presence of an H.E.Co. Engineer or Inspector.
- FORMS**: Make of good sound lumber, of sufficient strength, water tight and conforming to shape and dimensions indicated on drawings.
- The Hawaiian Electric Co. Inc. to furnish and Contractor to install, for each manhole:
 - A - 2-5/8" ϕ x 8'-0" copperweld ground rods.
 - B - Standard 28" manhole frame and cover. (H.E. Standard)
- Slope manhole floor down 1" toward sump.
- All work shall be subject to inspection by the Hawaiian Electric Co. Inc.; and/or Division of Highways, State of Hawaii; and/or Division of Engineering, City & County of Honolulu.
- All materials shall be new and shall be manufactured in the United States.
- For number, size, and exact location of ducts entrances and pulling irons, refer to project drawings.

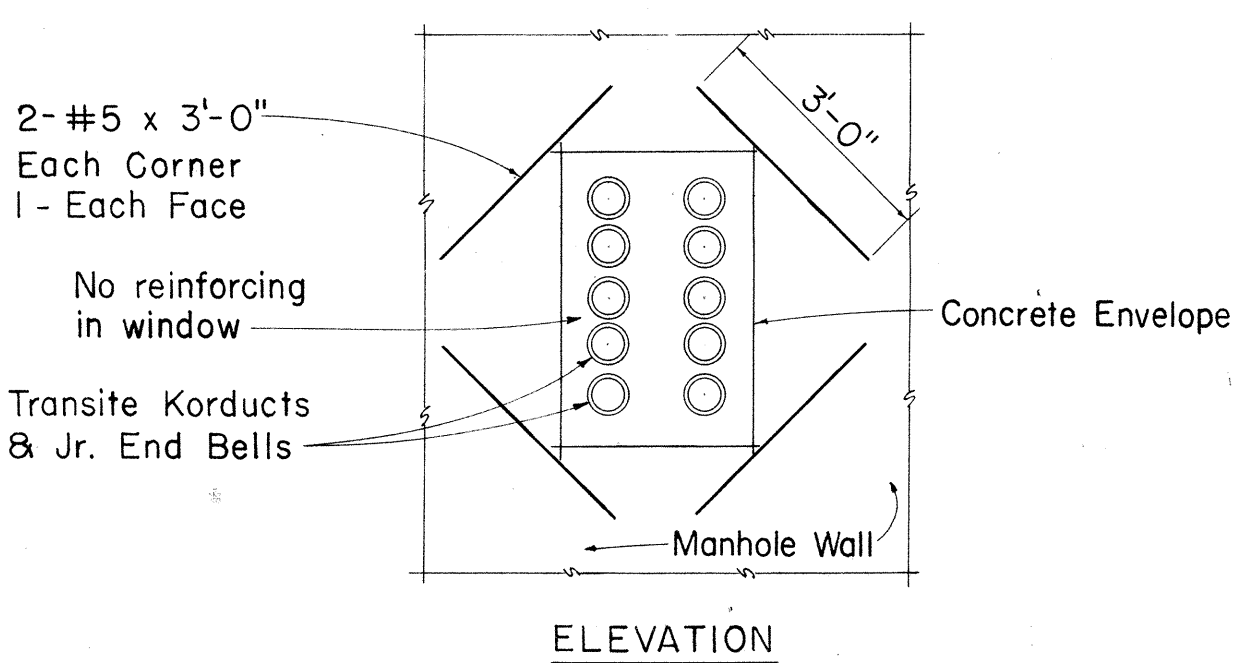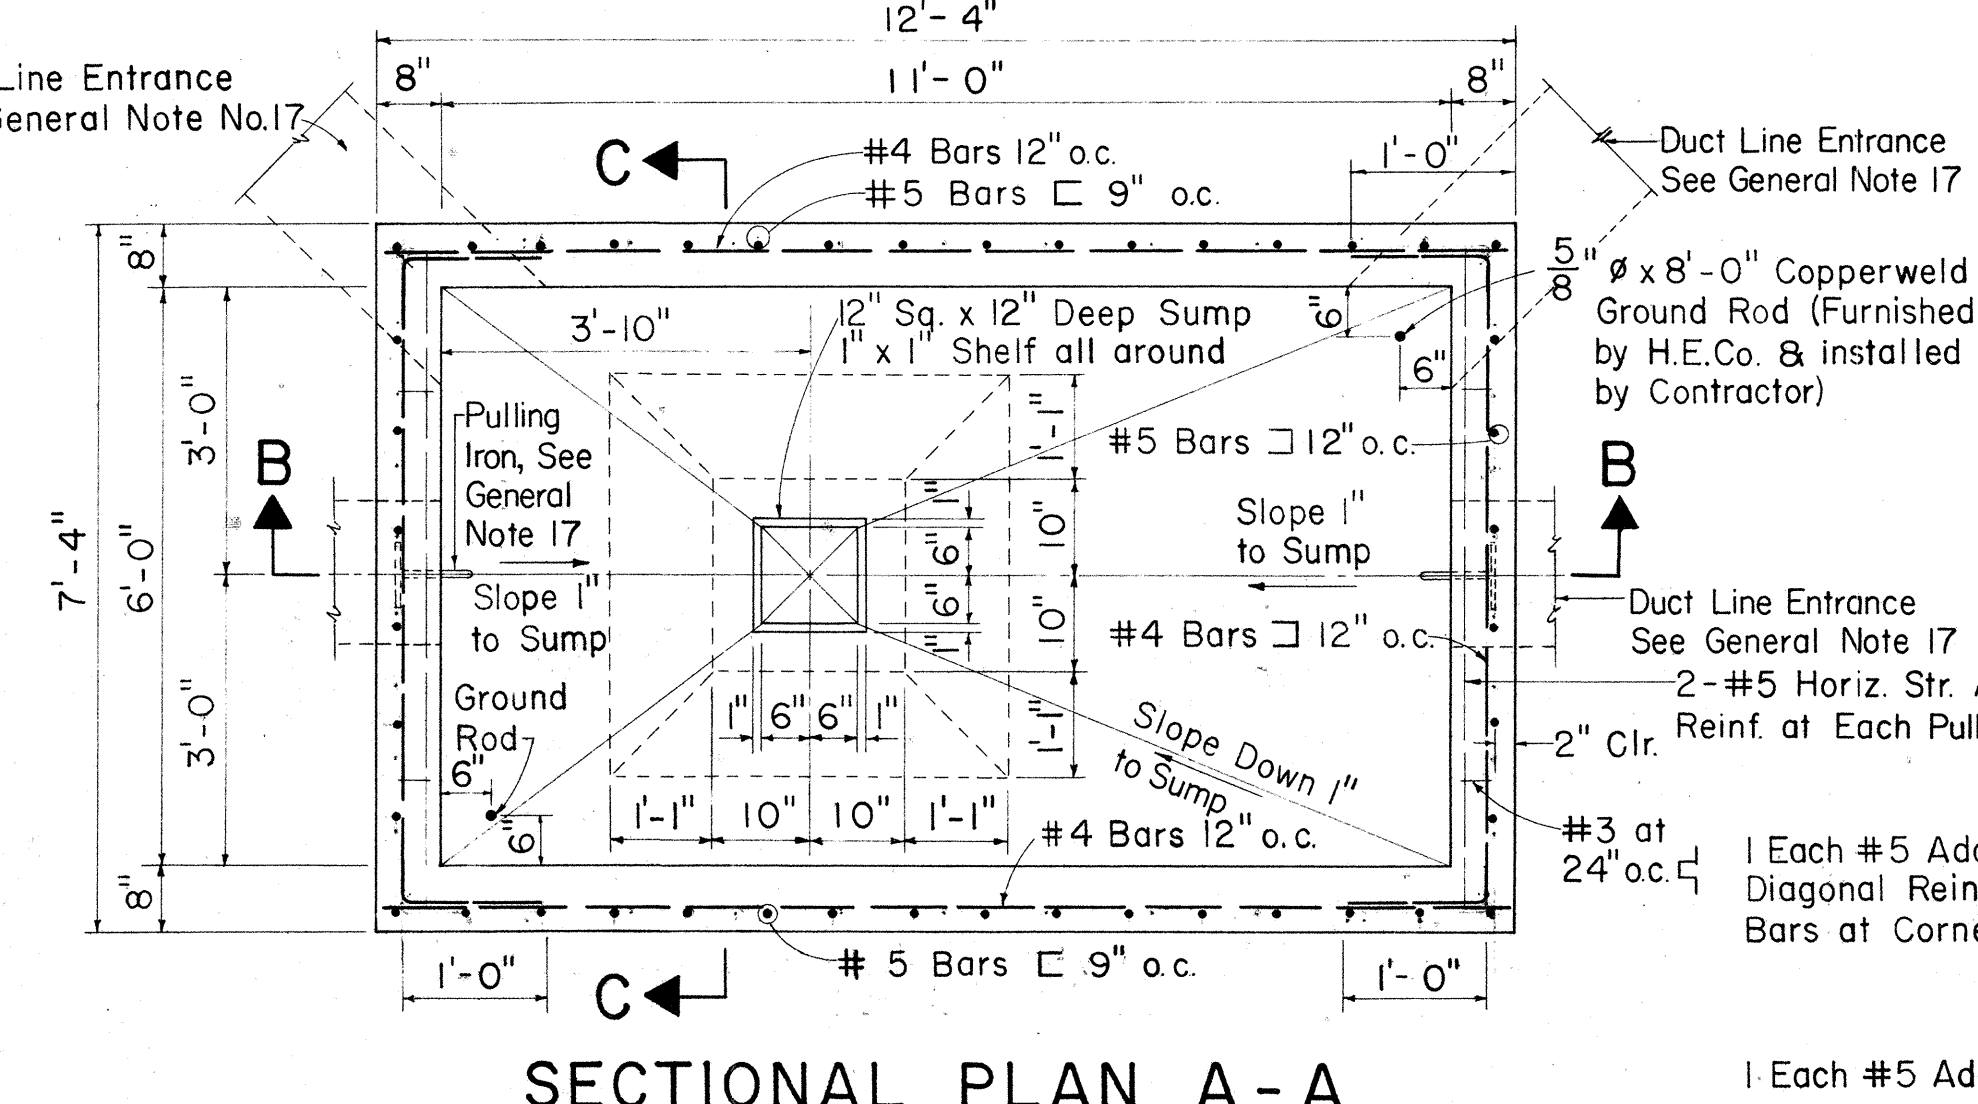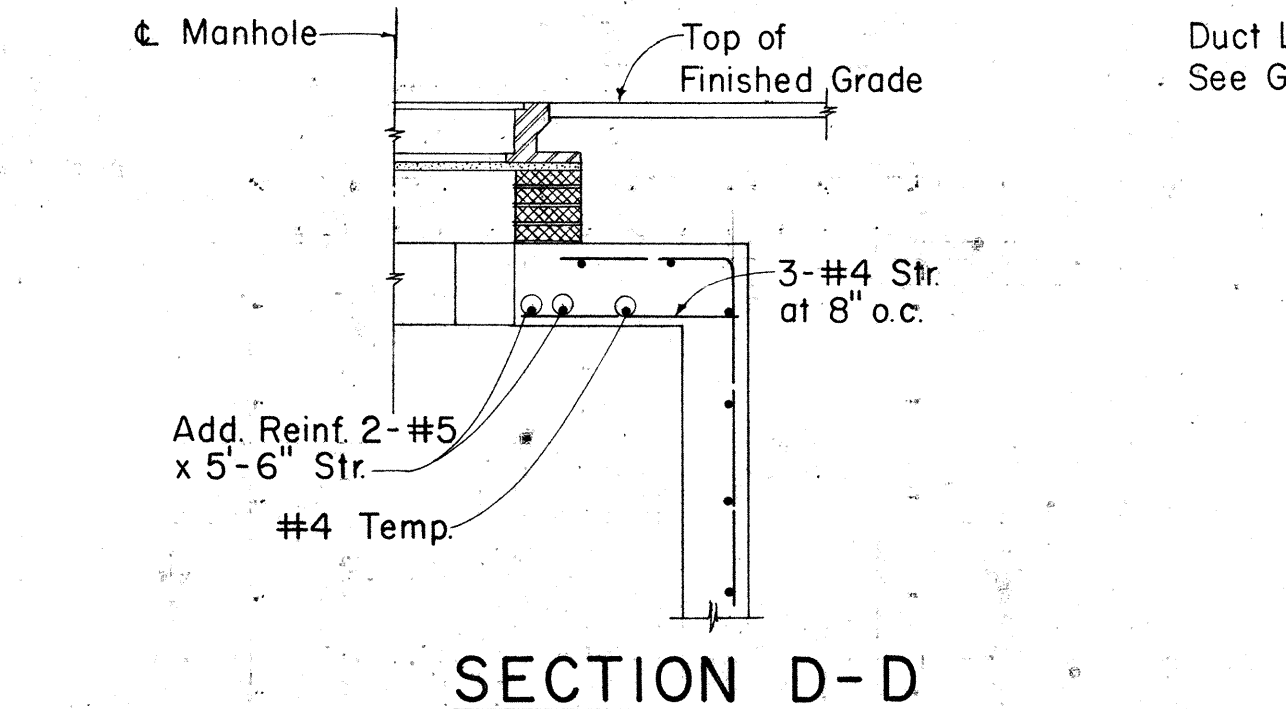


REINFORCING AT DUCT WINDOW

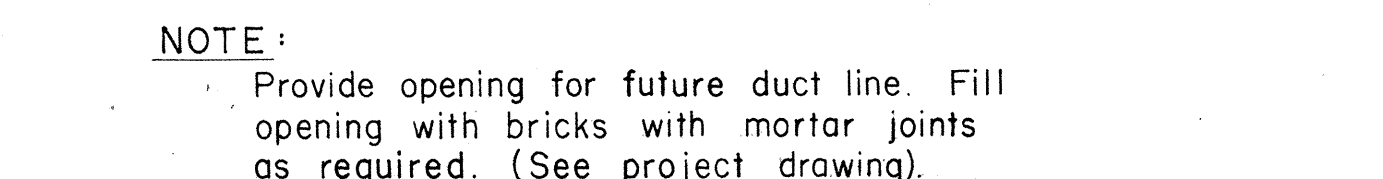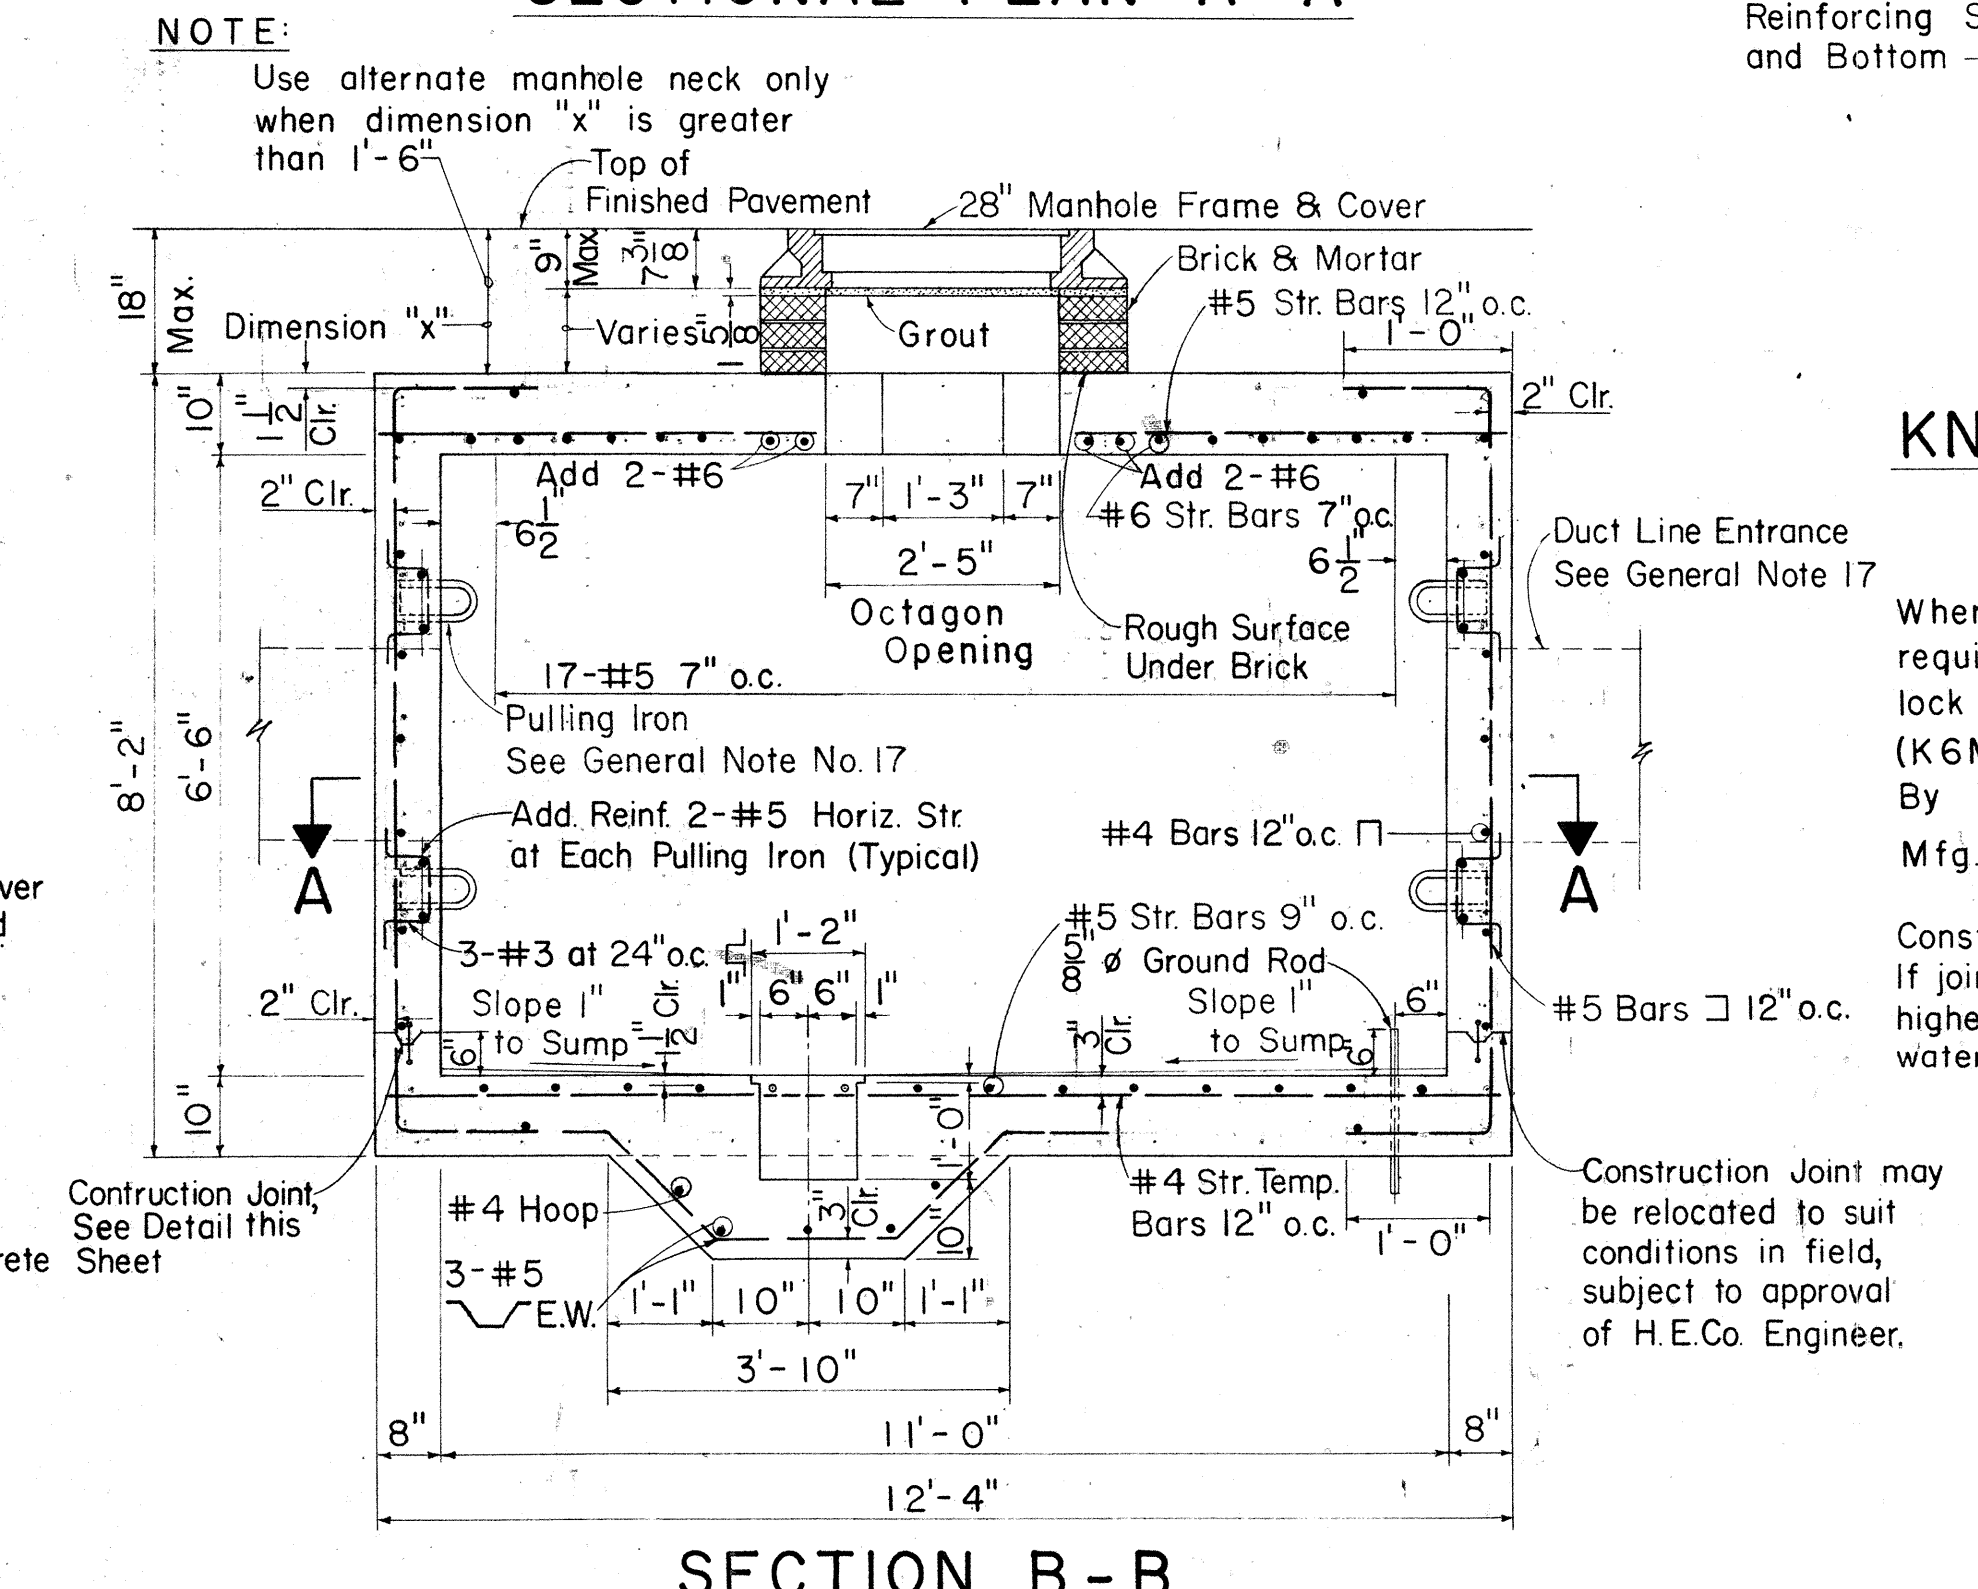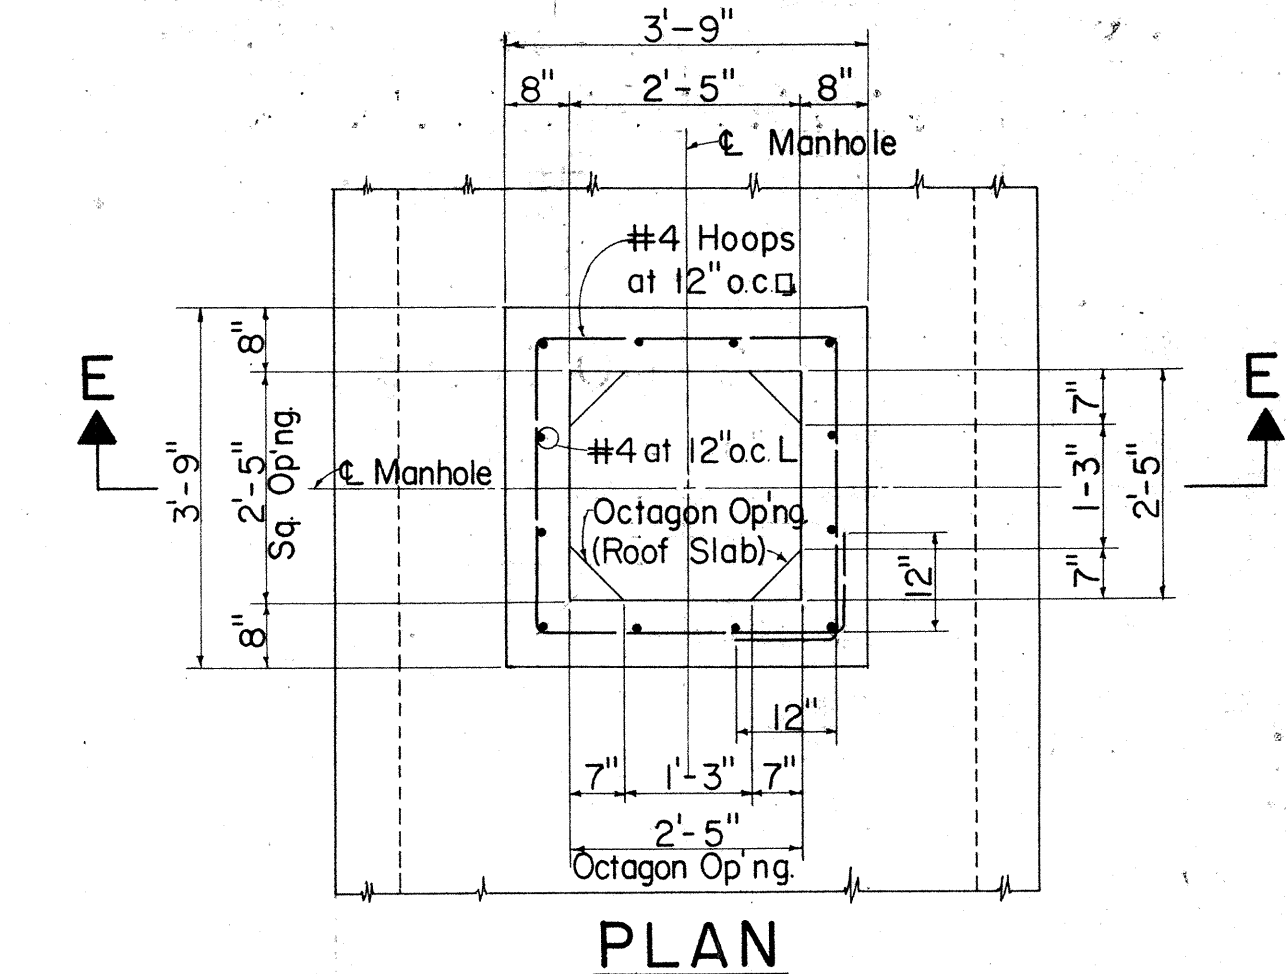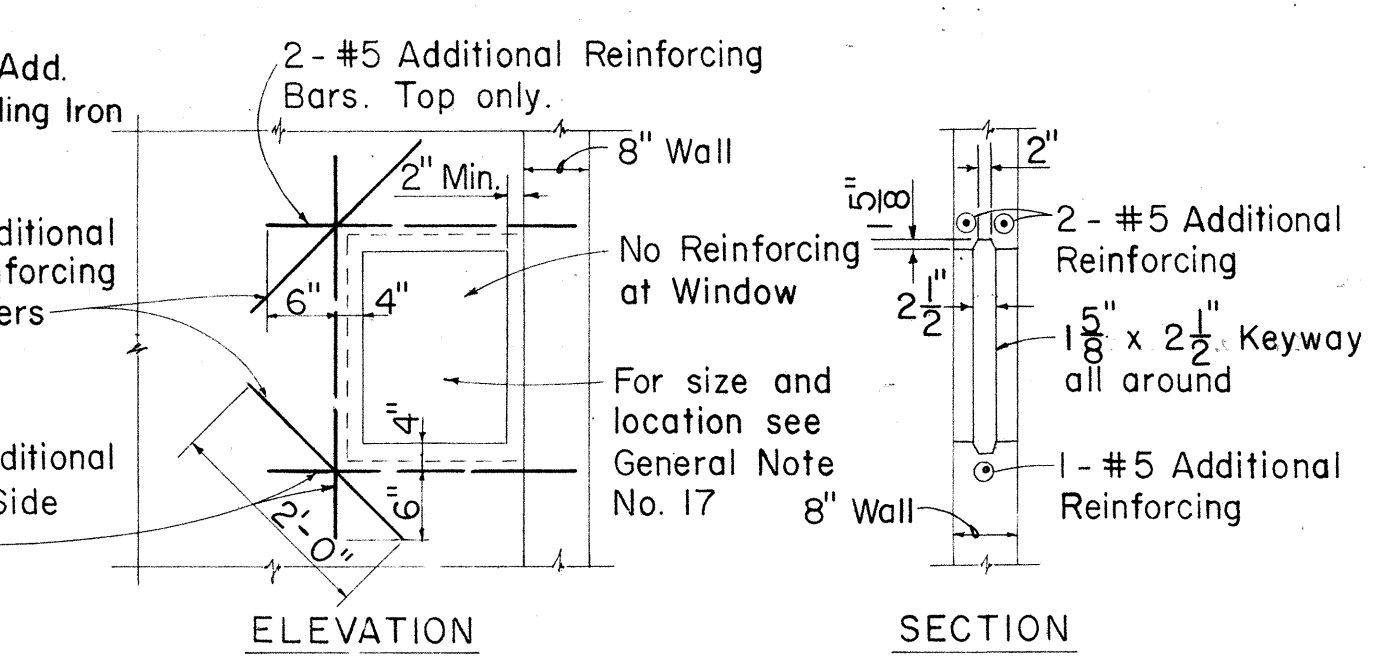

NOTE: Provide opening for future duct line. Fill opening with bricks with mortar joints as required. (See project drawing).

KNOCKOUT FOR FUTURE DUCT LINE

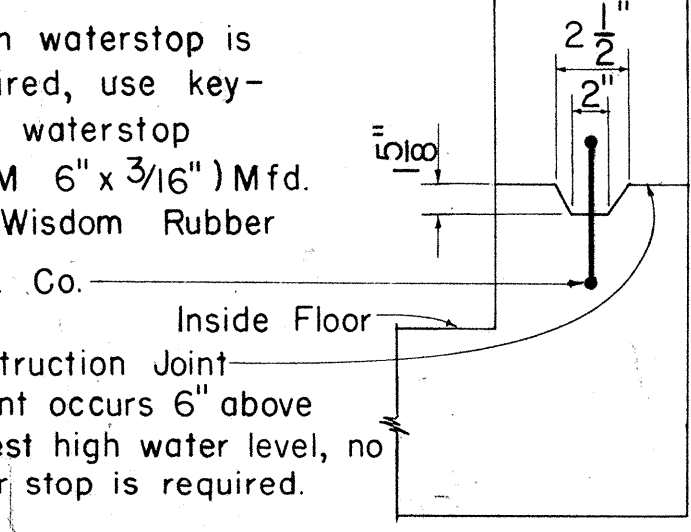

TYPICAL DETAIL OF CONSTRUCTION JOINT AND KEYWAY

REINFORCED CONCRETE QUANTITIES

QUANTITY OF MATERIALS FOR DEPTH "D"=5'-0"	
Total Concrete	= 11.8 Cu. Yds.
Total Reinf. Steel	= 1,363 Lbs.
QUANTITY OF MATERIALS FOR ALTERNATE NECK "D"=1'-0"	
Concrete	= 0.29 Cu. Yds.
Reinf. Steel	= 39 Lbs.
MATERIALS FOR 6" DEPTH OF 8" THICK WALL	
Concrete	= 0.45 Cu. Yds.
Reinf. Steel	= 37 Lbs.

REFERENCE DRAWINGS

- U-10082 - Standard H.E.Co. 28" Manhole Frame and Cover.
- 18585 - Underground Ductline Construction Standards - Details.
- 18585A - Underground Ductline Construction Standards - Specifications.

FOR USE IN AREAS SUBJECT TO PRESENT AND FUTURE VEHICULAR TRAFFIC

HECo., Inc. Drawing Number

18775

STATE OF HAWAII
DEPARTMENT OF TRANSPORTATION
HIGHWAYS DIVISION

STANDARD DETAILS
MANHOLE TYPE No. 1
(6'-0" x 11'-0")
UNDERGROUND STANDARDS

Scales: Not to Scale

SHEET NO. 16 OF 17 SHEETS

DATE	_____
SURVEY PLOTTED BY	_____
DRAWN BY	_____
TRACED BY	_____
NOTED BY	_____
CHECKED BY	_____
ORIGINAL PLAN	_____
NOTE BOOK	_____
No.	_____

SECTION E-E ALTERNATE MANHOLE NECK

SECTION B-B

FED. ROAD DIST. NO.	STATE	FED. AID PROJ. NO.	FISCAL YEAR	SHEET NO.	TOTAL SHEETS
HAWAII	HAWAII	1-HI-1(15)2	1969	61	181

FOR 25', & 30' POLES WITH 8'-0" ANCHOR RODS				
"A"	"B"	"C"		"D" = ("A" + "B")
LEAD-ANCHOR ROD TO C.O.F POLE	ANCHOR ROD TO C.O.F HOLE	VERTICAL DEPTH 18" D.M.	24" D.M.	TOTAL DISTANCE POLE TO HOLE
5'-0"	1'-8"	7'-1"	7'-4"	6'-8"
10'-0"	3'-0"	6'-7"	7'-0"	13'-0"
15'-0"	4'-0"	6'-1"	6'-6"	19'-0"
20'-0"	4'-8"	5'-6"	5'-10"	24'-8"
25'-0"	5'-2"	4'-11"	5'-4"	30'-2"
FOR 35' THRU 70' POLES WITH 8'-0" ANCHOR RODS				
5'-0"	1'-0"	7'-3"	7'-4"	6'-0"
10'-0"	1'-11"	7'-1"	7'-3"	11'-11"
15'-0"	2'-8"	6'-9"	7'-1"	17'-8"
20'-0"	3'-3"	6'-6"	6'-10"	23'-3"
25'-0"	3'-10"	6'-2"	6'-7"	28'-10"
FOR 40' THRU 70' POLES WITH 1 1/4" x 10'-0" ANCHOR RODS				
5'-0"	1'-7"		9'-4"	6'-7"
10'-0"	3'-0"		9'-0"	13'-0"
15'-0"	4'-2"		8'-6"	19'-2"
20'-0"	5'-3"		7'-11"	25'-3"
25'-0"	6'-2"		7'-3"	31'-2"

D. M. = Deadman

TABLE 2 ANCHOR ROD - ANCHOR SLUG - SQUARE WASHER COMBINATION							
H.E. CODE NO.	ANCHOR ROD	WORKING TENSION 1/2 ULT (LBS.)	H.E. CODE NO.	CONC. ANC. (IN.)	H.E. CODE NO.	WASHER SIZE	QTY.
617	5/8" x 8'-0" Steel	8,000	518	18	2320	4" x 4" x 3/16"	2
615	5/8" x 8'-0" Cu Cov Stl	9,250	518	18	**	3" x 3" x 1/8"	2
618	3/4" x 8'-0" Steel	11,500	518	18	2330	6" x 6" x 3/8"	1
619	1" x 8'-0" Steel	18,000	524	24	2331	6" x 6" x 1/2"	1
616	1" x 8'-0" Cu Cov Stl	22,500	524	24	**	4" x 4" x 3/16"	2
613	1 1/4" x 10'-0" Steel	29,000	524	24	2330	6" x 6" x 3/8"	2


** Use bronze square washers included in anchor rod assembly on copper covered steel (Cu Cov Stl) anchor rods.

ANCHORING DATA

STATE OF HAWAII
DEPARTMENT OF TRANSPORTATION
HIGHWAYS DIVISION
STANDARD DETAILS
H.E. Co. AND H.T. Co.
ANCHOR DETAILS AND
ANCHORING DATA

Scales: As Noted Date


SHEET No. 17 OF 17 SHEETS

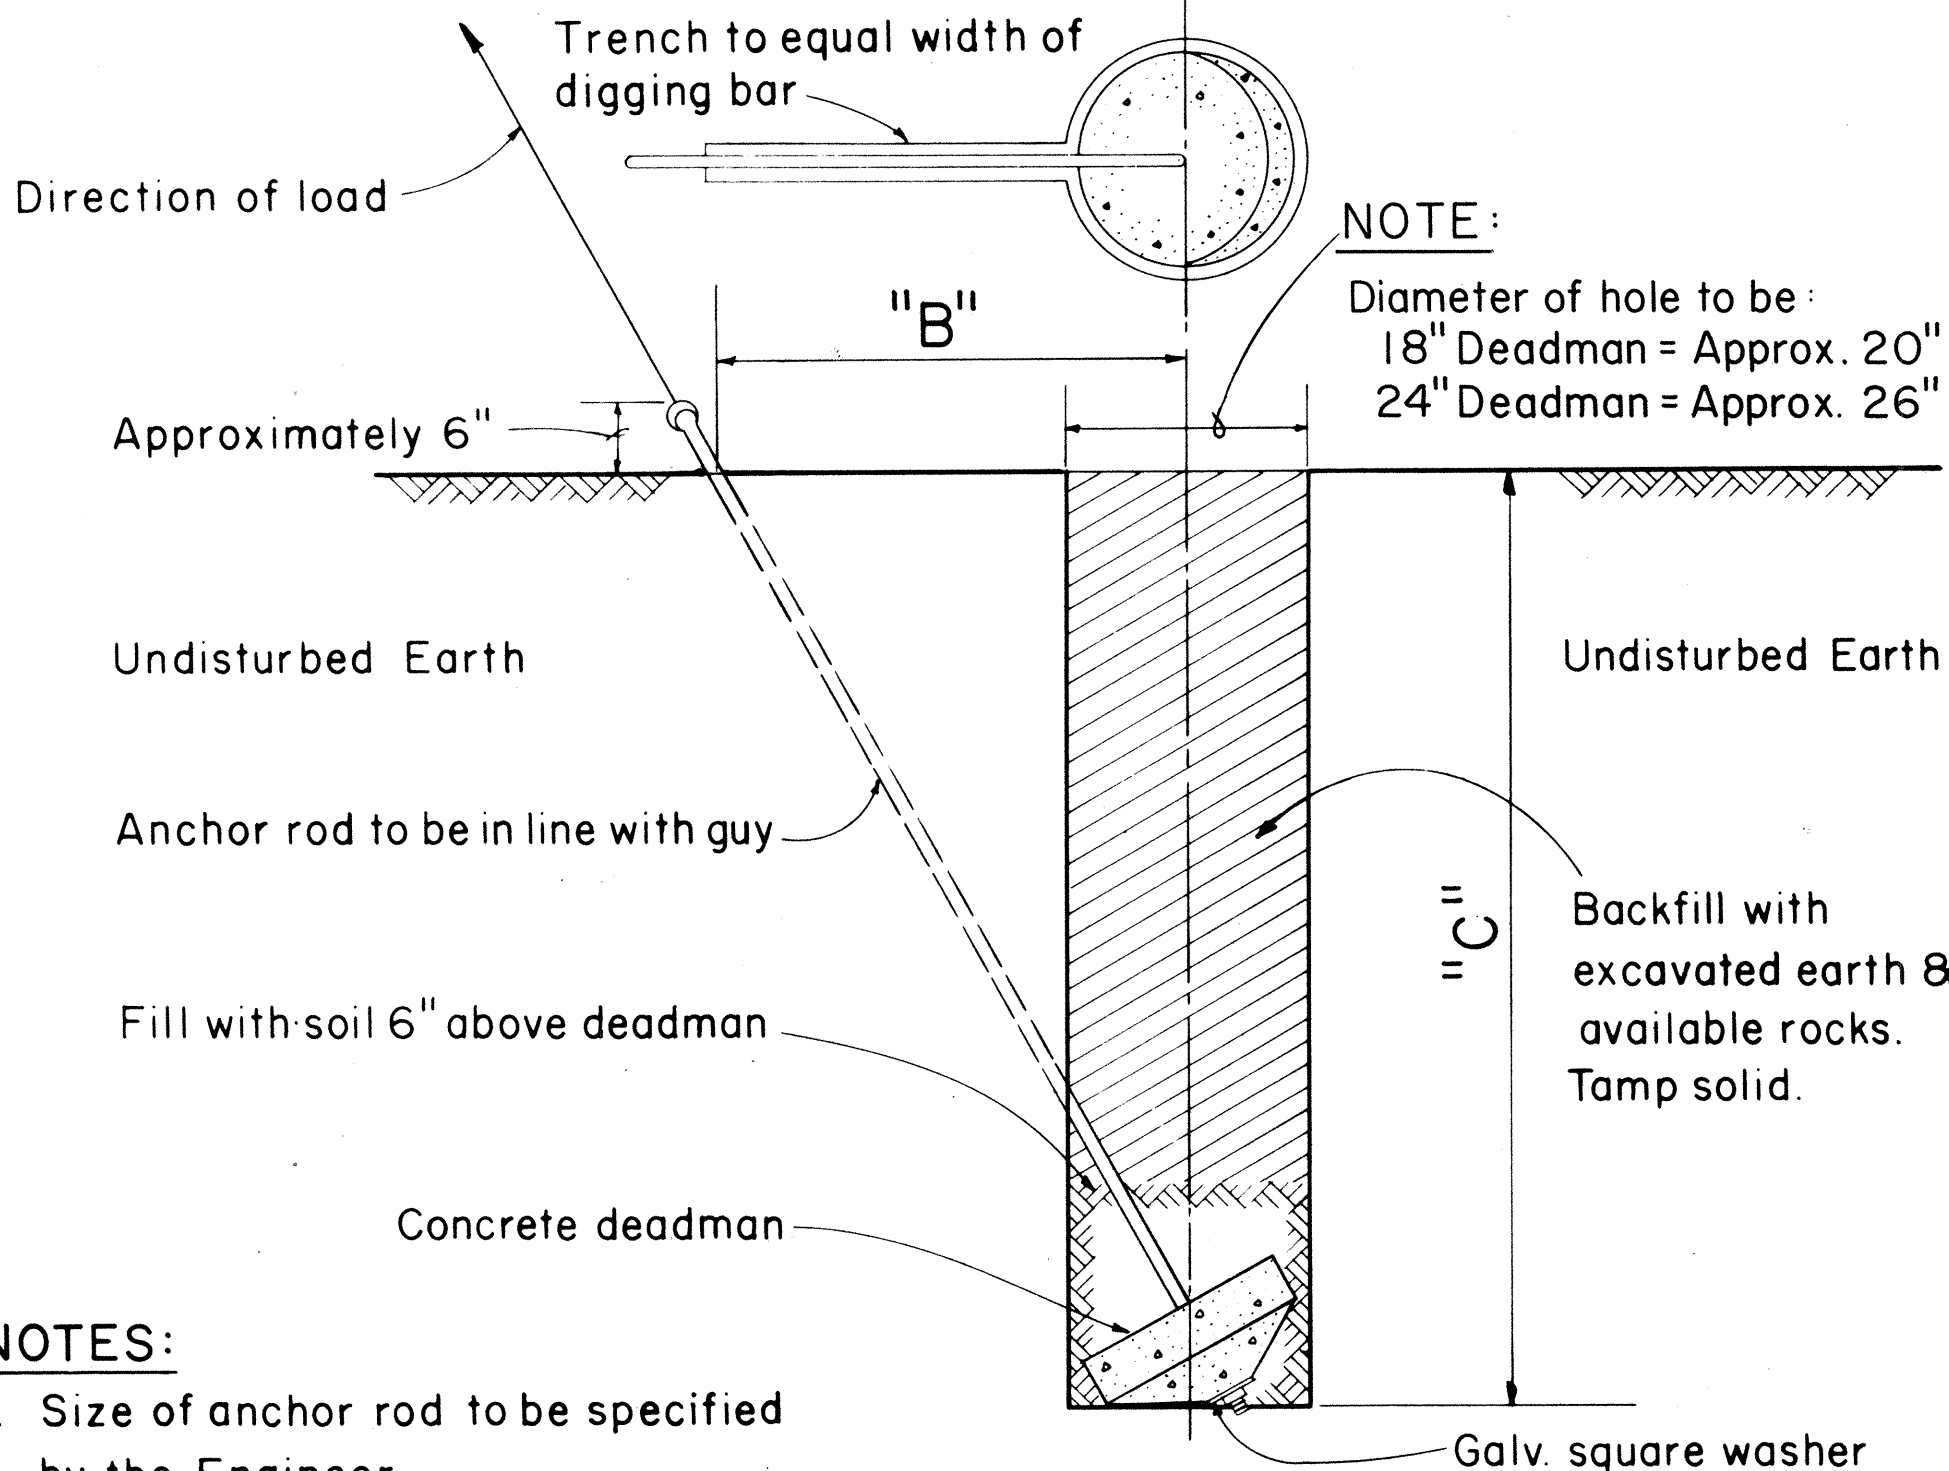

- NOTES:
- Size of anchor rod to be specified by the Engineer
 - Use Anchoring Data.


GUY ANCHOR DEADMAN

Scale: 3/4" = 1' - 0"

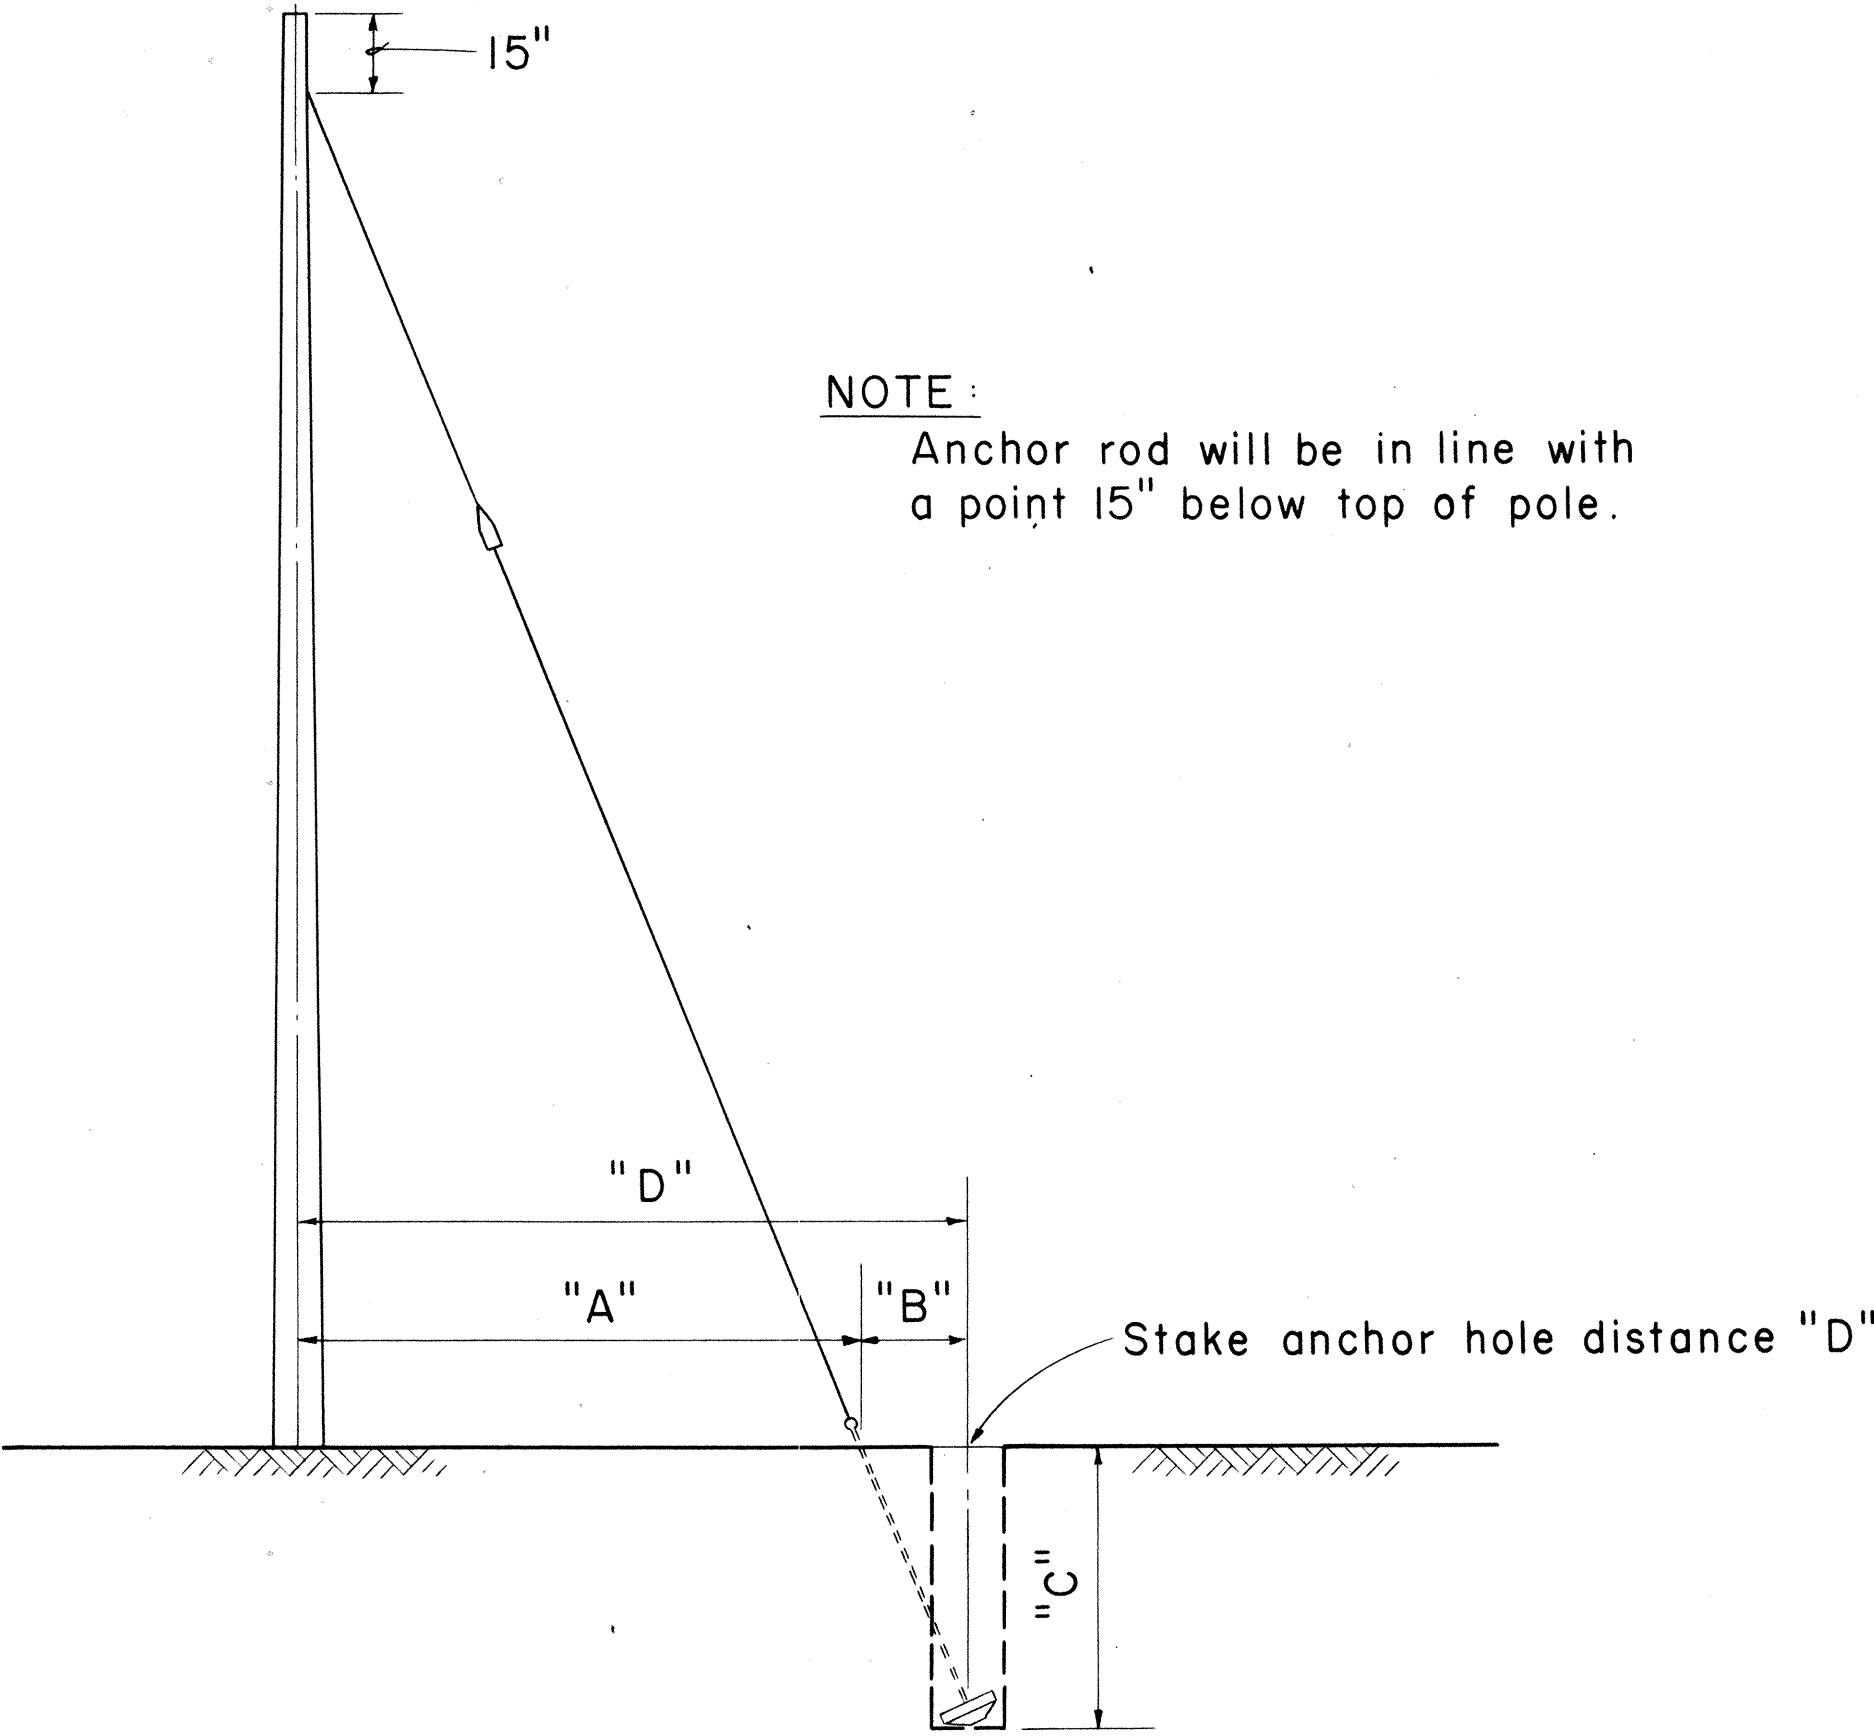

- NOTE:
- Anchor rod will be in line with a point 15" below top of pole.


Not to Scale

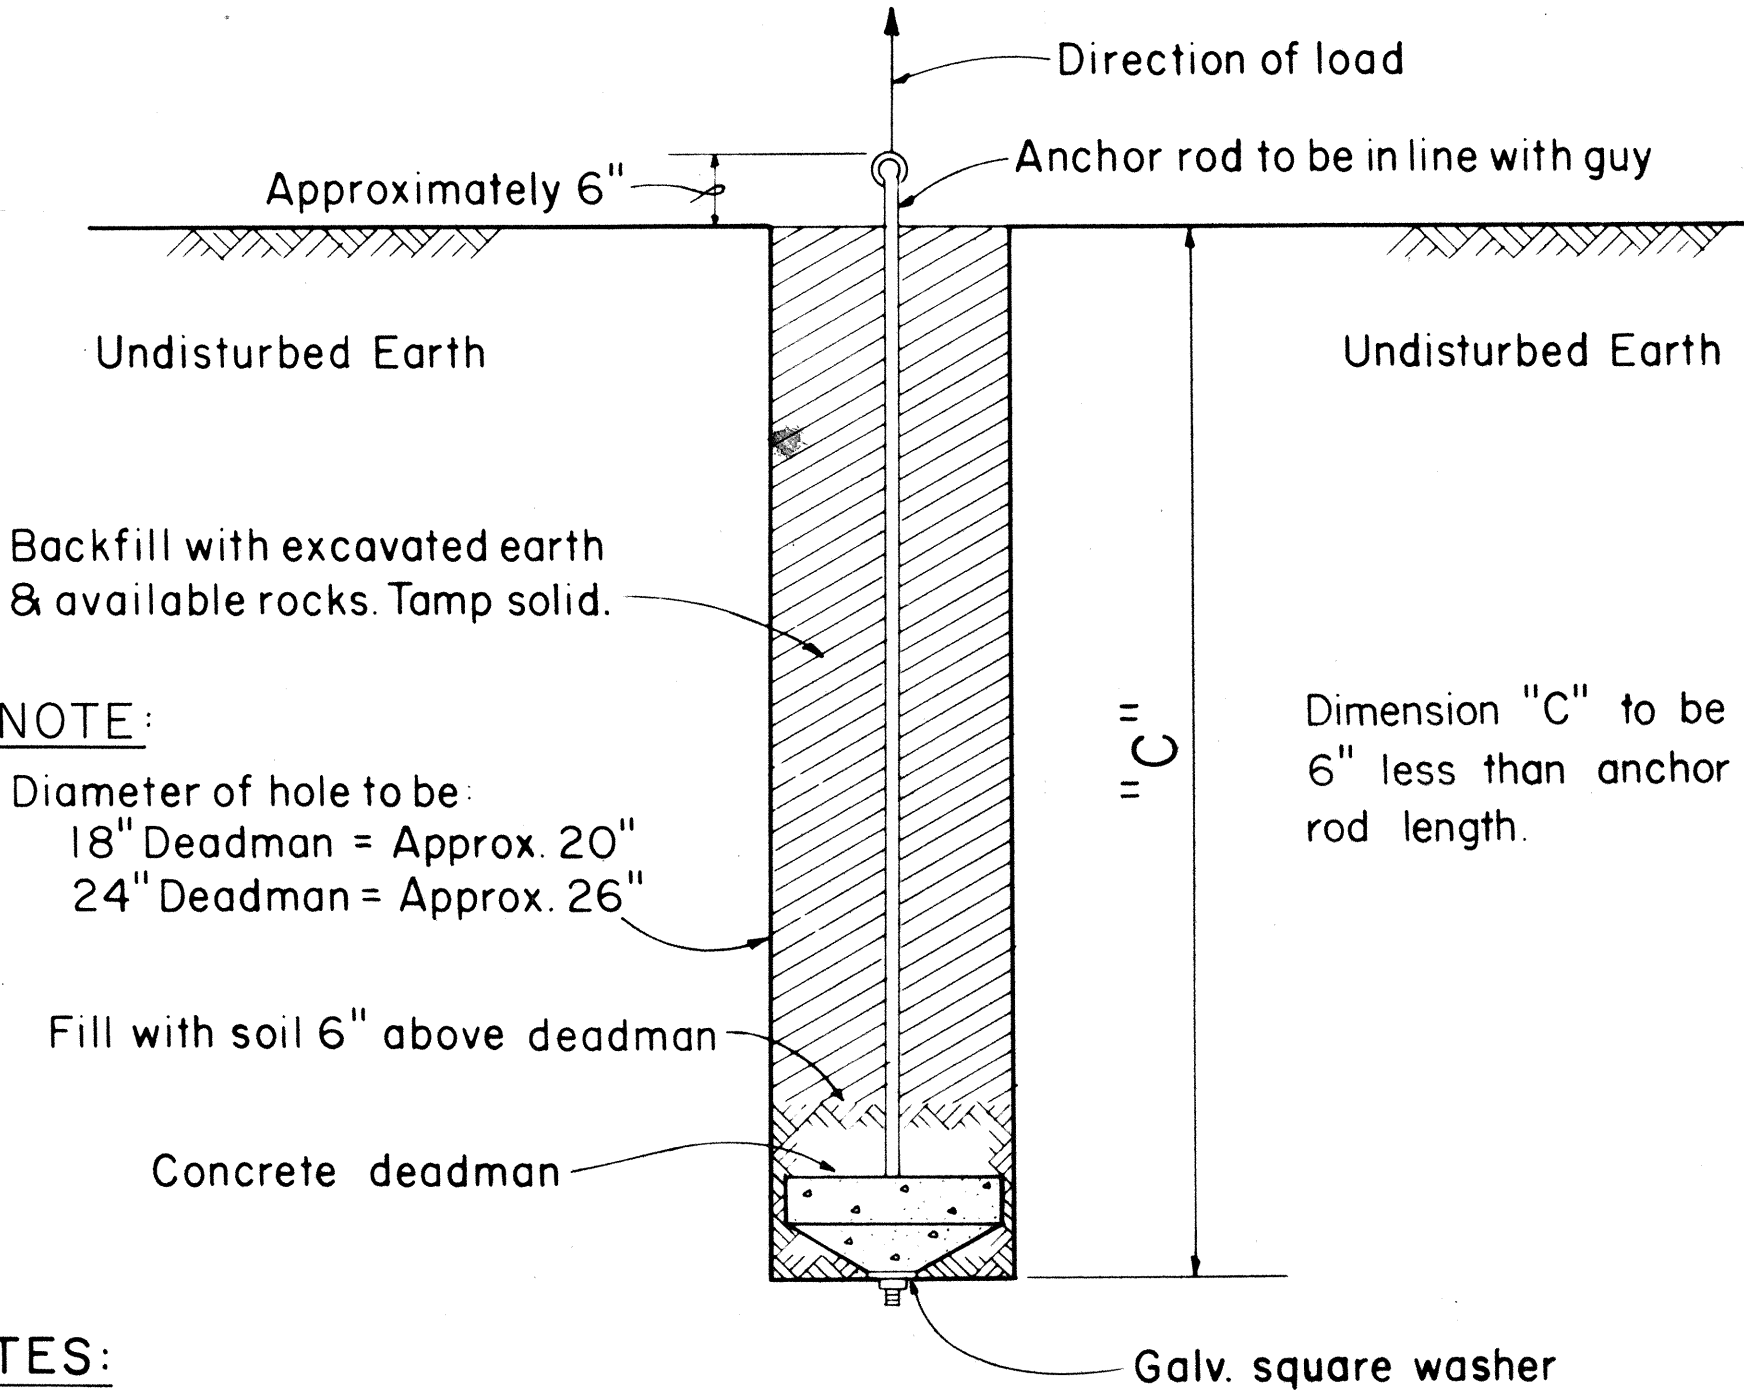

- NOTES:
- Size of anchor rod to be specified by the Engineer.
 - Use Anchoring Data.

SIDE - WALK ANCHOR

Scale: 3/4" = 1' - 0"

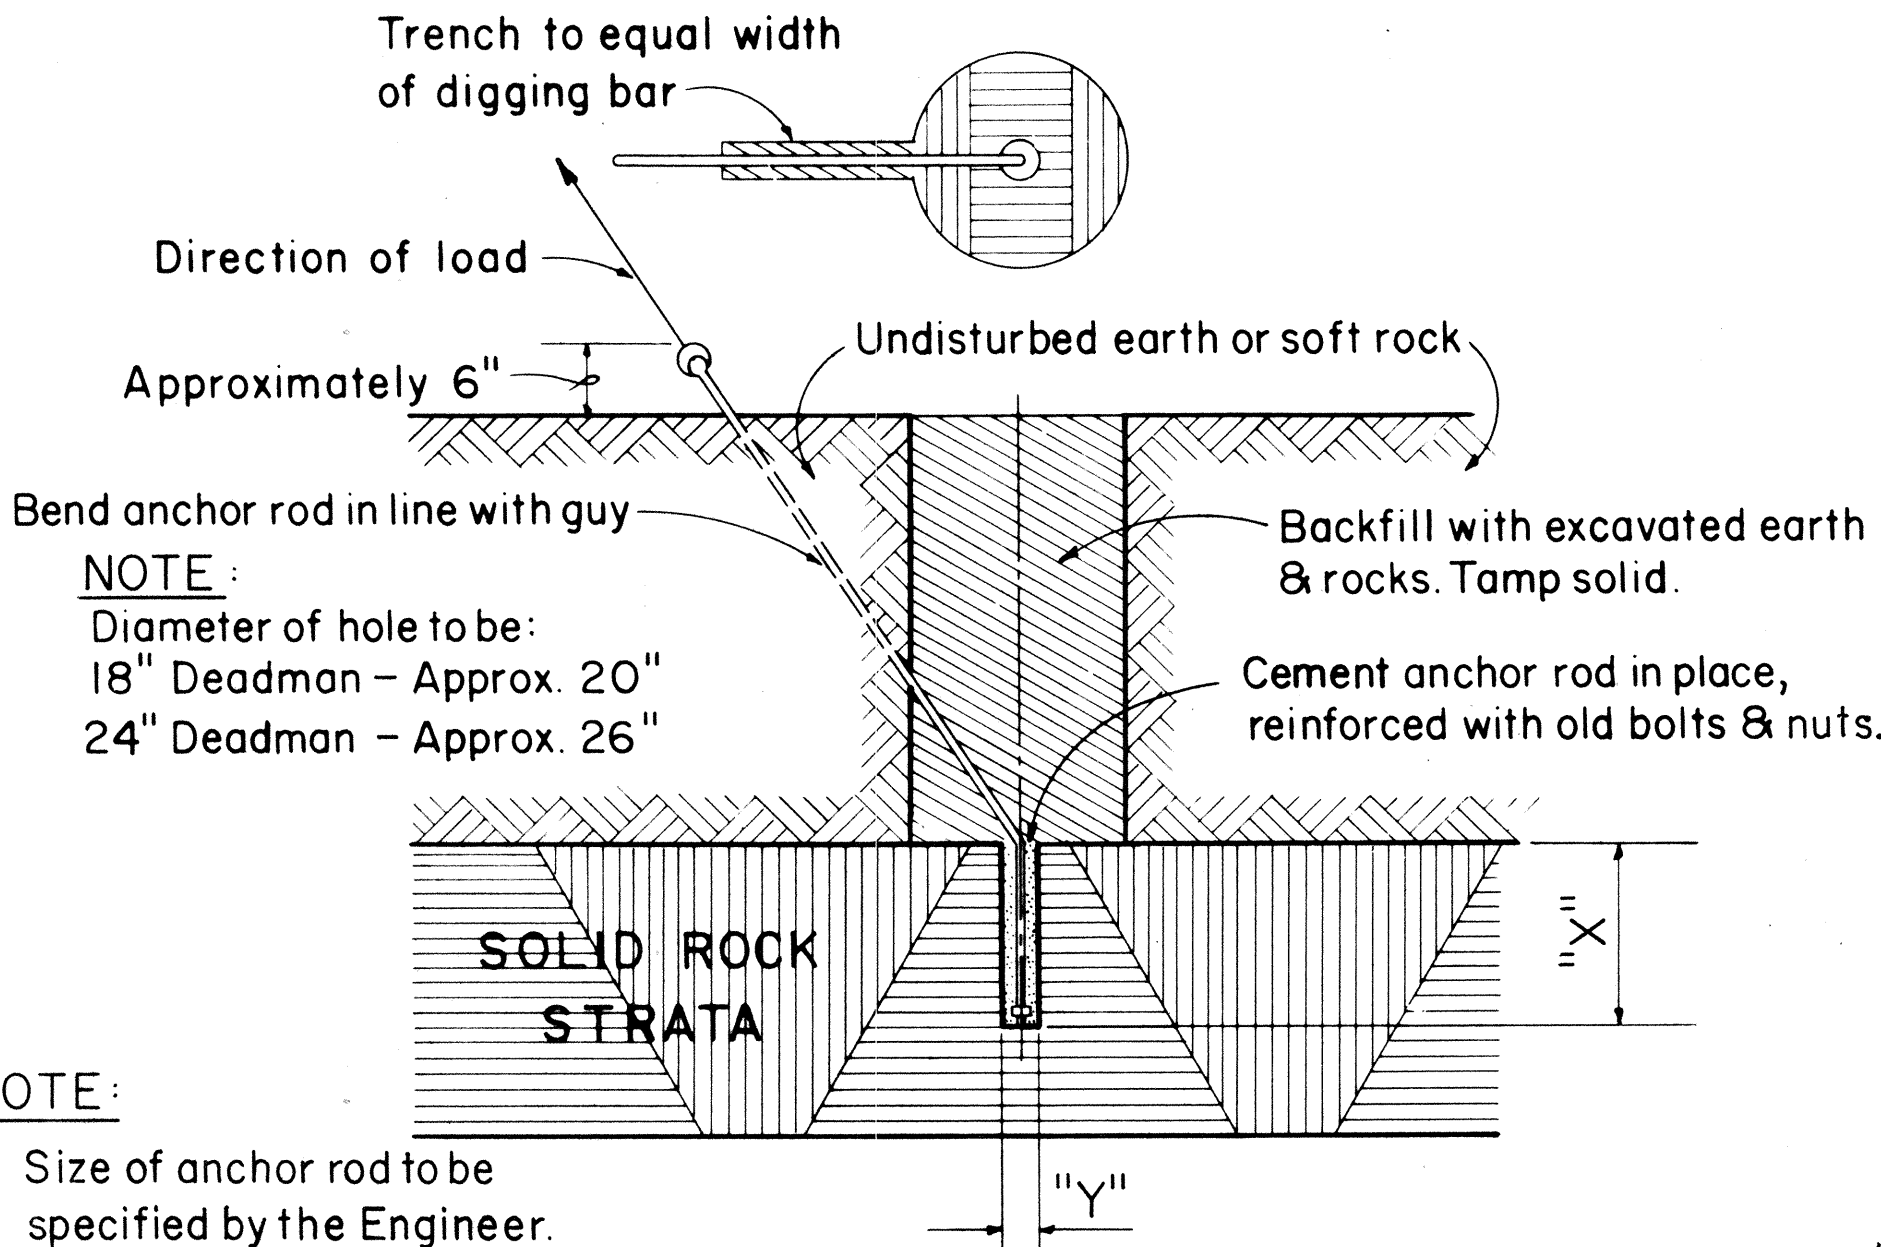

- NOTE:
- Size of anchor rod to be specified by the Engineer.
 - "X" Should not be less than 24".
If "X" is less than 24" complete hole & install anchor.
 - "Y" 5/8" Anchor rod drill 2" hole
3/4" Anchor rod drill 2" hole
1" Anchor rod drill 2 1/2" hole
1 1/4" Anchor rod drill 3" hole
 - Use Anchoring Data.

ROCK ANCHOR

Not to Scale