	INDEX TO DRAWINGS
DWG NO.	DESCRIPTION
1	TITLE SHEET
2 - 3	SHEET INDEX
4	STANDARD PLANS SUMMARY
5 - 82	CIVIL DRAWINGS
83 - 101	STRUCTURAL PLANS
102 - 121	ELECTRICAL PLANS
122 - 126	LANDSCAPE PLANS

STATE OF HAWAII

## DEPARTMENT OF TRANSPORTATION


HIGHWAYS DIVISION HONOLULU, HAWAII

"AS-BUILT" DESIGN BUILD

PLANS FOR

INTERSTATE ROUTE H-1 SHOULDER WORK AND PORTLAND CEMENT CONCRETE PAVEMENT REHABILITATION VICINITY OF WAIMALU TO VICINITY OF HALAWA PHASE 2 - SHOULDER WORK FEDERAL AID PROJECT NO. NH-H1-1(274)

> DISTRICTS OF EWA AND HONOLULU ISLAND OF OAHU

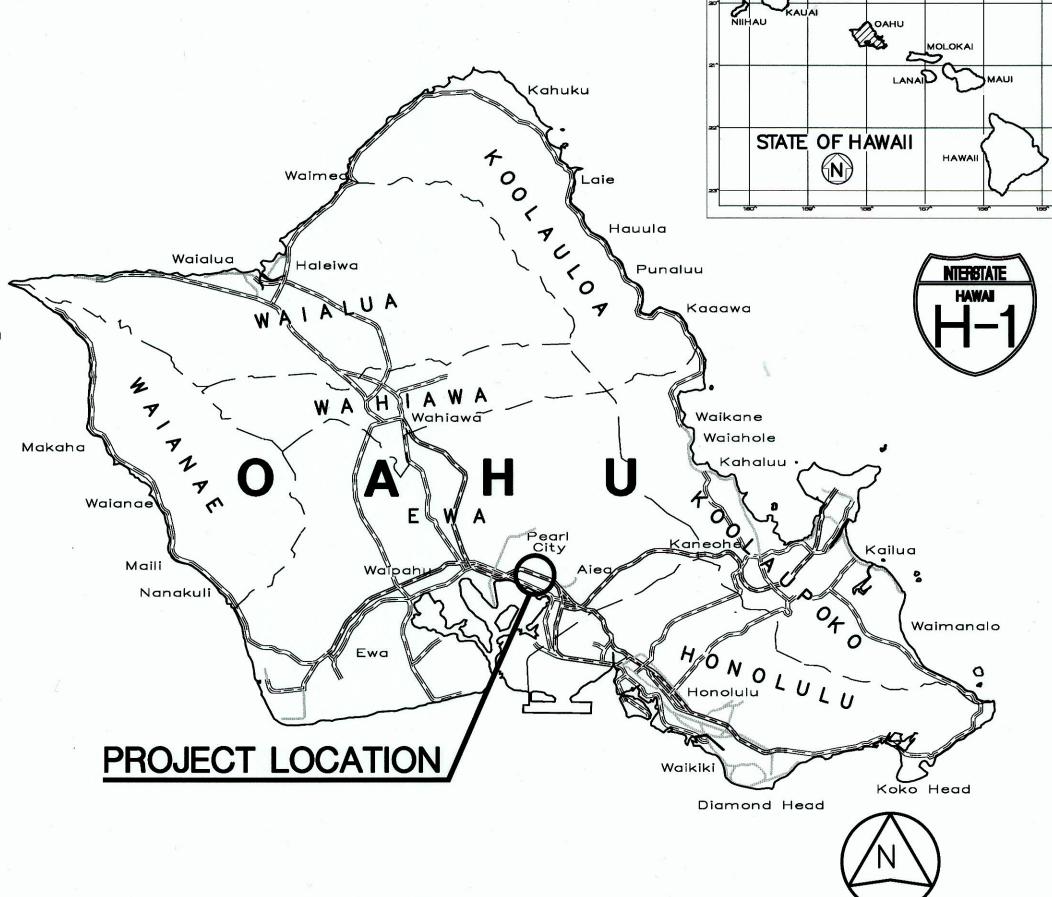


FED. ROAD DIST. NO.

FED. AID PROJ. NO.

NH-H1-1(274)

YEAR

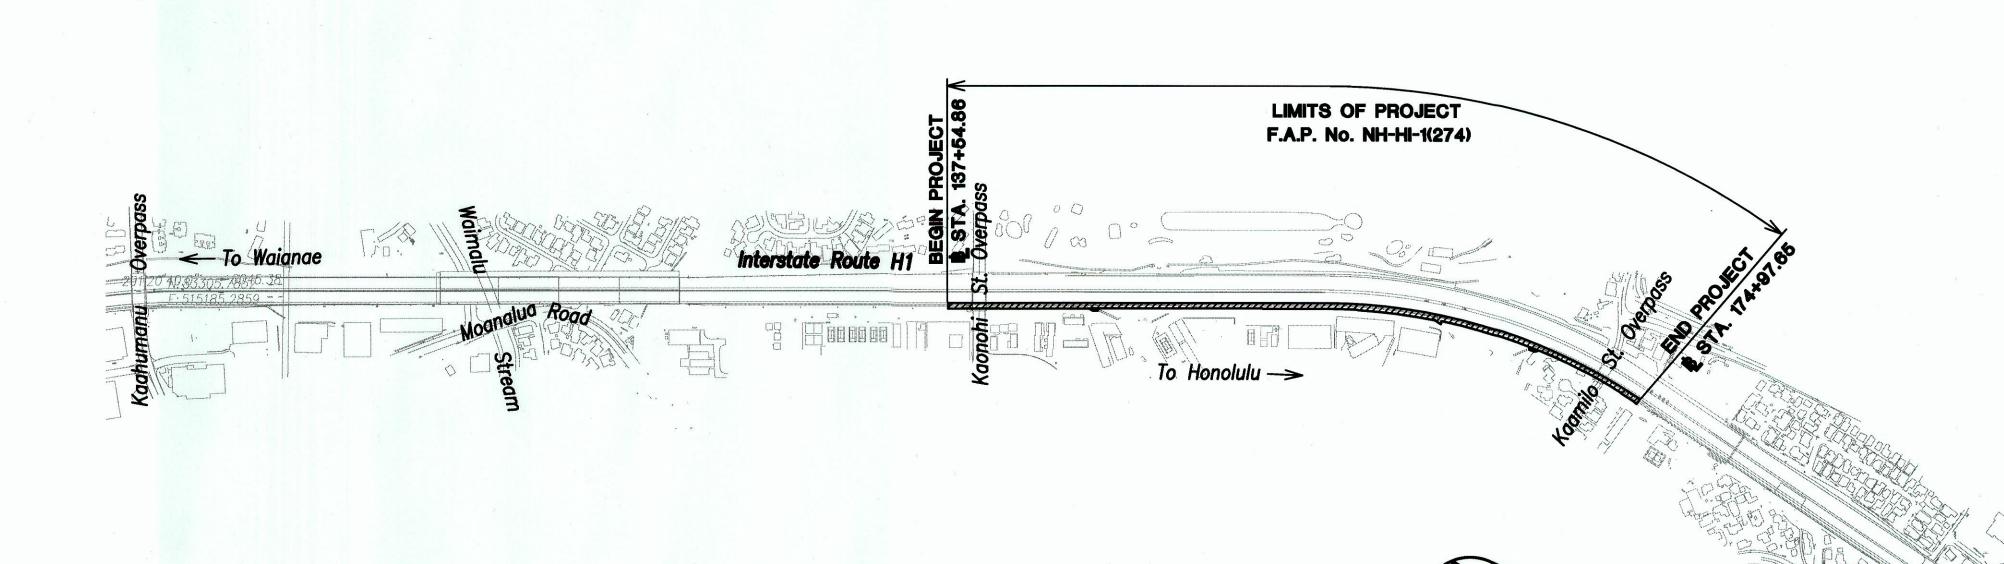

5 2.5 0

SCALE IN HUNDRED FEET

**LAYOUT PLAN** 

**NET LENGTH OF PROJECT - 0.71 MILES** 

**GROSS LENGTH OF PROJECT - 0.71 MILES** 

FEDERAL AID PROJECTS PREVIOUSLY CONSTRUCTED OR UNDER CONSTRUCTION

MILE POST <u>11.56</u> TO MILE POST <u>12.27</u>

DESIGN DESIGNATION
ADT (2016)260,300
DESIGN ADT (2036)300,200
DHV21,000
D (DESIGN)60/40
T (DESIGN)4.5%
T <sub>24</sub> 4.0%
V60 MPH

DEPARTMENT OF TRANSPORTATION STATE OF HAWAII APPROVED: DIR. OF TRANSPORTATION DATE

SCALE IN MILES