

GENERAL UTILITY NOTES (ALL UTILITIES)

1. THE CONTRACTOR SHALL BE LIABLE FOR DAMAGE TO ANY EXISTING UTILITY AND STRUCTURE.
2. THE EXISTENCE AND LOCATION OF UNDERGROUND UTILITIES, APPURTENANCES AND STRUCTURES AS SHOWN ON THE PLANS ARE BASED ON EXISTING RECORDS OF VARYING DEGREES OF ACCURACY AND COMPLETENESS. THEY ARE NOT GUARANTEED AS TO THE LOCATION SHOWN OR THAT OTHER OBSTACLES MAY NOT BE ENCOUNTERED IN THE COURSE OF WORK. THE CONTRACTOR SHALL ASSUME THAT EXISTING UTILITIES MAY EXIST, ALTHOUGH NOT SHOWN.
3. IN ORDER TO AVOID CONFLICTS WITH FUTURE AND PROPOSED IMPROVEMENTS FOR KEEHI INTERCHANGE SUCH AS STRUCTURE FOOTINGS, UTILITIES, DRAINAGE FACILITIES, ETC., THE PROPOSED UTILITY FACILITIES SHALL BE CONSTRUCTED AT THE LOCATIONS SHOWN ON THE PLANS.
4. RESTORATION OF EXISTING PAVEMENTS AND IMPROVEMENTS UNAVOIDABLY DEMOLISHED DUE TO WORK ON UTILITY RECONSTRUCTIONS SHALL BE INCIDENTAL TO THE VARIOUS CONTRACT ITEMS. RESTORATION SHALL BE TO ORIGINAL OR BETTER CONDITION.
5. THE CONTRACTOR SHALL POST A CUSTODIAN DURING PUMPING OPERATIONS. CUSTODIAN MUST BE KNOWLEDGEABLE IN THE OPERATION OF THE PUMP IN USE IN ORDER TO AVOID PROLONGED DELAYS SHOULD THE PUMP MALFUNCTION.
6. THE CONTRACTOR SHALL GIVE ALL PROPERTY OWNERS FIVE (5) DAYS NOTICE BEFORE ENTERING INTO THEIR RESPECTIVE PROPERTIES.

TELEPHONE NOTES

(HAWAIIAN TELEPHONE CO.,)

1. THE CONTRACTOR SHALL GIVE HTCO, IN WRITING, AT LEAST 20 WORKING DAYS ADVANCE NOTICE OF INTENT TO COMMENCE WORK ON THE TELEPHONE SYSTEM.
2. EXISTING TELEPHONE FACILITIES SHOWN ON THESE PLANS ARE APPROXIMATE ONLY. THE CONTRACTOR SHALL VERIFY THEIR ACTUAL LOCATION AND SHALL MAKE ADJUSTMENTS TO THE PROPOSED FACILITY AS DIRECTED BY HTCO.
3. HTCO WILL COORDINATE ITS WORK WITH THE CONTRACTOR IN SUCH A MANNER AS TO EXPEDITE CONSTRUCTION.
4. STAKE-OUT OF NEW DUCTS SHALL BE DONE BY THE CONTRACTOR, AND VERIFIED BY HTCO.
5. ALL SPLICE PITS AND DUCTS SHALL BE INSTALLED BY THE CONTRACTOR.
6. ALL TELEPHONE DUCTS ENCASED IN CONCRETE JACKET UNLESS OTHERWISE SPECIFIED. ALL DUCTS SHALL BE INSPECTED AND APPROVED BY HTCO BEFORE CONCRETE PLACEMENT. ADVANCE NOTICE OF AT LEAST 24 HOURS SHALL BE GIVEN BEFORE PLACING CONCRETE.
7. POLES, ANCHORS, AND CABLES WILL BE REMOVED BY HTCO.
8. HTCO TO FURNISH THE CONTRACTOR FOR PROPER INSTALLATION, ALL MANHOLE FRAMES AND COVERS; ALL PULLING IRONS, AND GROUND RODS; ALL PVC DUCTS AND SPREADERS.
9. THE CONTRACTOR SHALL FURNISH AND INSTALL ALL HARDWARE WITHIN THE BRIDGE STRUCTURE.

GAS NOTES

(GASCO, INC.)

1. THE CONTRACTOR SHALL GIVE GASCO, INC., IN WRITING AT LEAST 14 CALENDAR DAYS ADVANCE NOTICE OF INTENT TO COMMENCE WORK ON THE GAS SYSTEM.
2. THE CONTRACTOR SHALL VERIFY THE EXACT LOCATIONS AND DEPTHS OF EXISTING GAS LINES PRIOR TO START OF CONSTRUCTION OPERATIONS. THE CONTRACTOR SHALL CALL GASCO, INC. A MINIMUM OF 48 HOURS BEFORE STARTING EXCAVATION TO ARRANGE FOR FIELD LOCATION OF ALL EXISTING GAS PIPE LINES. THE TELEPHONE NUMBER IS 548-2126 DURING BUSINESS HOURS, AND 548-2123 AFTER HOURS. THE CONTRACTOR SHALL EXCAVATE AND BACKFILL AROUND GAS PIPE LINES IN THE PRESENCE OF A GASCO, INC. REPRESENTATIVE. ALL BACKFILL WITHIN SIX INCHES OF GAS LINE SHALL BE SELECT CUSHION MATERIAL APPROVED BY GASCO, INC.
3. FOR RELOCATION OF ANY GAS PIPE LINE, THE CONTRACTOR SHALL NOTIFY GASCO, INC. 5 WORKING DAYS BEFORE STARTING WORK. THE CONTRACTOR SHALL PROVIDE THE NECESSARY EXCAVATION AND BACKFILL, ARRANGE FOR TRAFFIC PERMITS AND RESTORE SIDEWALK PAVEMENT OR OTHER IMPROVEMENTS. THE CONTRACTOR SHALL PERFORM ALL NECESSARY EXCAVATION FOR NEW GAS LINES UNTIL THE NEW LINES ARE IN SERVICE.
4. THE CONTRACTOR SHALL FURNISH ALL MATERIALS, LABOR AND EQUIPMENT FOR PERFORMING ALL NECESSARY EXCAVATION, BACKFILL, AND CONCRETE WORK NECESSARY FOR THE INSTALLATION OF NEW GAS PIPES IN TRENCH AND ADJUSTMENTS TO EXISTING GAS PIPES AND APPURTENANCES. GASCO WILL PROVIDE ALL MATERIALS, LABOR AND EQUIPMENT FOR THE INSTALLATION OF THE GAS LINE IN TRENCHES, INCLUDING FABRICATION, WELDING, AND TESTING.
5. EXISTING FRAME AND COVER FROM THE RECONSTRUCTED GASCO BLOCK VALVE STRUCTURE SHALL BE SALVAGED, CLEANED AND DELIVERED BY THE CONTRACTOR TO:
GAS COMPANY SALES/DISTRIBUTION,
515 KAMAKEE STREET
ATTN: MR. YUKIO HARAMOTO OR MR. GEORGE FUJITA
6. THE GASCO, INC. GAS PIPE LINES IN THE PROJECT AREA ARE PLASTIC COATED AND CATHODICALLY PROTECTED. THE CONTRACTOR SHALL BE EXTREMELY CAREFUL WHEN WORKING NEAR THESE GAS PIPE LINES.
7. THE CONTRACTOR SHALL NOTIFY GASCO, INC. IMMEDIATELY AFTER ANY DAMAGE HAS BEEN CAUSED TO EXISTING GAS PIPELINES, THEIR COATINGS OR THEIR CATHODIC PROTECTION DEVICES. REPAIR WORK ON THIS DAMAGE WILL BE DONE BY GASCO, INC. WITH PAYMENT FOR THIS WORK TO BE BORNE BY THE CONTRACTOR.
8. MINIMUM VERTICAL OR HORIZONTAL CLEARANCE BETWEEN GAS PIPE LINES AND OTHER PIPELINES, CONDUITS, OR DUCTLINES SHALL BE 12 INCHES. ADEQUATE SUPPORT AND PROTECTION FOR GAS PIPE LINES EXPOSED IN THE TRENCH SHALL BE PROVIDED. SUCH SUPPORT AND PROTECTION WILL BE APPROVED BY GASCO, INC. IF THIS CLEARANCE CANNOT BE ATTAINED, THE GAS LINE SHALL BE PROTECTED WITH A GASCO, INC. - APPROVED INSULATION MATERIAL FURNISHED AND INSTALLED BY THE CONTRACTOR, AND THE WORK MUST BE APPROVED BY GASCO, INC.
9. THE CONTRACTOR SHALL WORK IN AN EXPEDITIOUS MANNER IN ORDER TO KEEP UNCOVERED GAS PIPE LINES EXPOSED FOR AS SHORT A PERIOD OF TIME AS POSSIBLE.

ELECTRIC NOTES


(HAWAIIAN ELECTRIC CO., INC.)

1. THE CONTRACTOR SHALL GIVE HECO IN WRITING AT LEAST 20 WORKING DAYS ADVANCE NOTICE OF INTENT TO COMMENCE WORK ON THE ELECTRICAL SYSTEM.
2. ALL EXISTING FACILITIES SHALL REMAIN IN PLACE UNTIL THE PROPOSED FACILITIES ARE INSTALLED. EXISTING ELECTRIC FACILITIES SHOWN ON THESE PLANS ARE APPROXIMATE ONLY. THE CONTRACTOR SHALL VERIFY THEIR ACTUAL LOCATIONS AND SHALL MAKE ADJUSTMENTS TO THE PROPOSED FACILITY AS DIRECTED BY HECO.
3. HECO WILL COORDINATE ITS WORK WITH THE CONTRACTOR IN SUCH A MANNER AS TO EXPEDITE CONSTRUCTION.
4. ALL MATERIALS REQUIRED FOR THE RELOCATION AND REARRANGEMENT OF THE HECO'S OVERHEAD FACILITIES WILL BE FURNISHED BY HECO.
5. THE CONTRACTOR SHALL FURNISH AND INSTALL ALL MATERIALS TO COMPLETE CONSTRUCTION OF THE UNDERGROUND DUCTLINE SYSTEM, INCLUDING RISER CONDUITS. ALL ELECTRIC DUCTS SHALL BE ENCASED IN CONCRETE JACKET UNLESS OTHERWISE SPECIFIED. ALL DUCTS AND CONDUITS SHALL BE INSPECTED AND APPROVED BY HECO PRIOR TO PLACING CONCRETE. THE CONTRACTOR SHALL NOTIFY HECO'S INSPECTION DIVISION (PHONE 548-4428) AT LEAST 24 HOURS PRIOR TO PLACING CONCRETE.
6. LOCATION AND DEPTH OF ALL HANDHOLES AND SWITCH MANHOLES SHALL BE VERIFIED AND APPROVED IN THE FIELD BY HECO PRIOR TO EXCAVATION, CONSTRUCTION OR INSTALLATION.
7. THE CONTRACTOR IS TO MANDREL TEST ALL DUCTLINES IN THE PRESENCE OF HECO'S INSPECTOR PRIOR TO ACCEPTANCE.
8. EXCAVATION OF POLE HOLES AND ANCHORS, INSTALLATION OF POLES AND ANCHORS, AND BACKFILL OF POLE HOLES AND ANCHORS WILL BE DONE BY HECO. STAKE OUT OF WOOD POLE AND ANCHOR LOCATIONS TO BE DONE BY THE CONTRACTOR AND VERIFIED BY HECO.
9. ELECTRIC DUCT BANKS SHALL ENTER AND LEAVE MANHOLES AT ZERO PERCENT SLOPE FOR A MINIMUM DISTANCE OF TEN FEET, UNLESS OTHERWISE SPECIFIED.
10. FOR ANCHOR STAKE OUT DETAILS SEE HECO PROJECT DWG. NO. ~~2443~~ 24859 & 24861 HECO TO PROVIDE CONTRACTOR WITH HECO PROJECT DWG. NO. ~~2443~~ 24859 & 24861
11. THE CONTRACTOR SHALL FURNISH AND INSTALL ALL MATERIALS TO COMPLETE CONSTRUCTION OF PVC DUCTS INSTALLED ON BRIDGES.

FED. ROAD DIST. NO.	STATE	FED. AID PROJ. NO.	FISCAL YEAR	SHEET NO.	TOTAL SHEETS
HAWAII	HAW	H-1(131):17	1977	173	394

DATE	_____
SURVEY PLOTTED BY	_____
DESIGNED BY	_____
NOTED BY	_____
CHECKED BY	_____
ORIGINAL PLAN	_____
NOTE BOOK	_____
NO.	_____


APPROVED:	
<i>B. Yukihiro</i> Hawaiian Telephone Co.,	<i>8-15-77</i> Date
<i>M. J. Karimots</i> Hawaiian Electric Co., Inc.	<i>8/10/77</i> Date
<i>Charles J. ...</i> Gasco, Inc.	<i>8/10/77</i> Date
STATE OF HAWAII DEPARTMENT OF TRANSPORTATION HIGHWAYS DIVISION GENERAL UTILITY NOTES INTERSTATE ROUTE H-1 PROJECT NO. H-1-1(131):17 NO SCALE DATE: AUG. 31, 1977 SHEET NO. U-1 OF U-23 SHEETS	

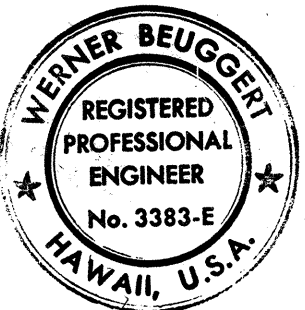

THIS WORK WAS PREPARED BY ME OR UNDER MY SUPERVISION.

Werner Beugger


FED. ROAD DIST. NO.	STATE	FED. AID PROJ. NO.	FISCAL YEAR	SHEET NO.	TOTAL SHEETS
HAWAII	HAW.	1-H1-1(131):17	1977	174	394

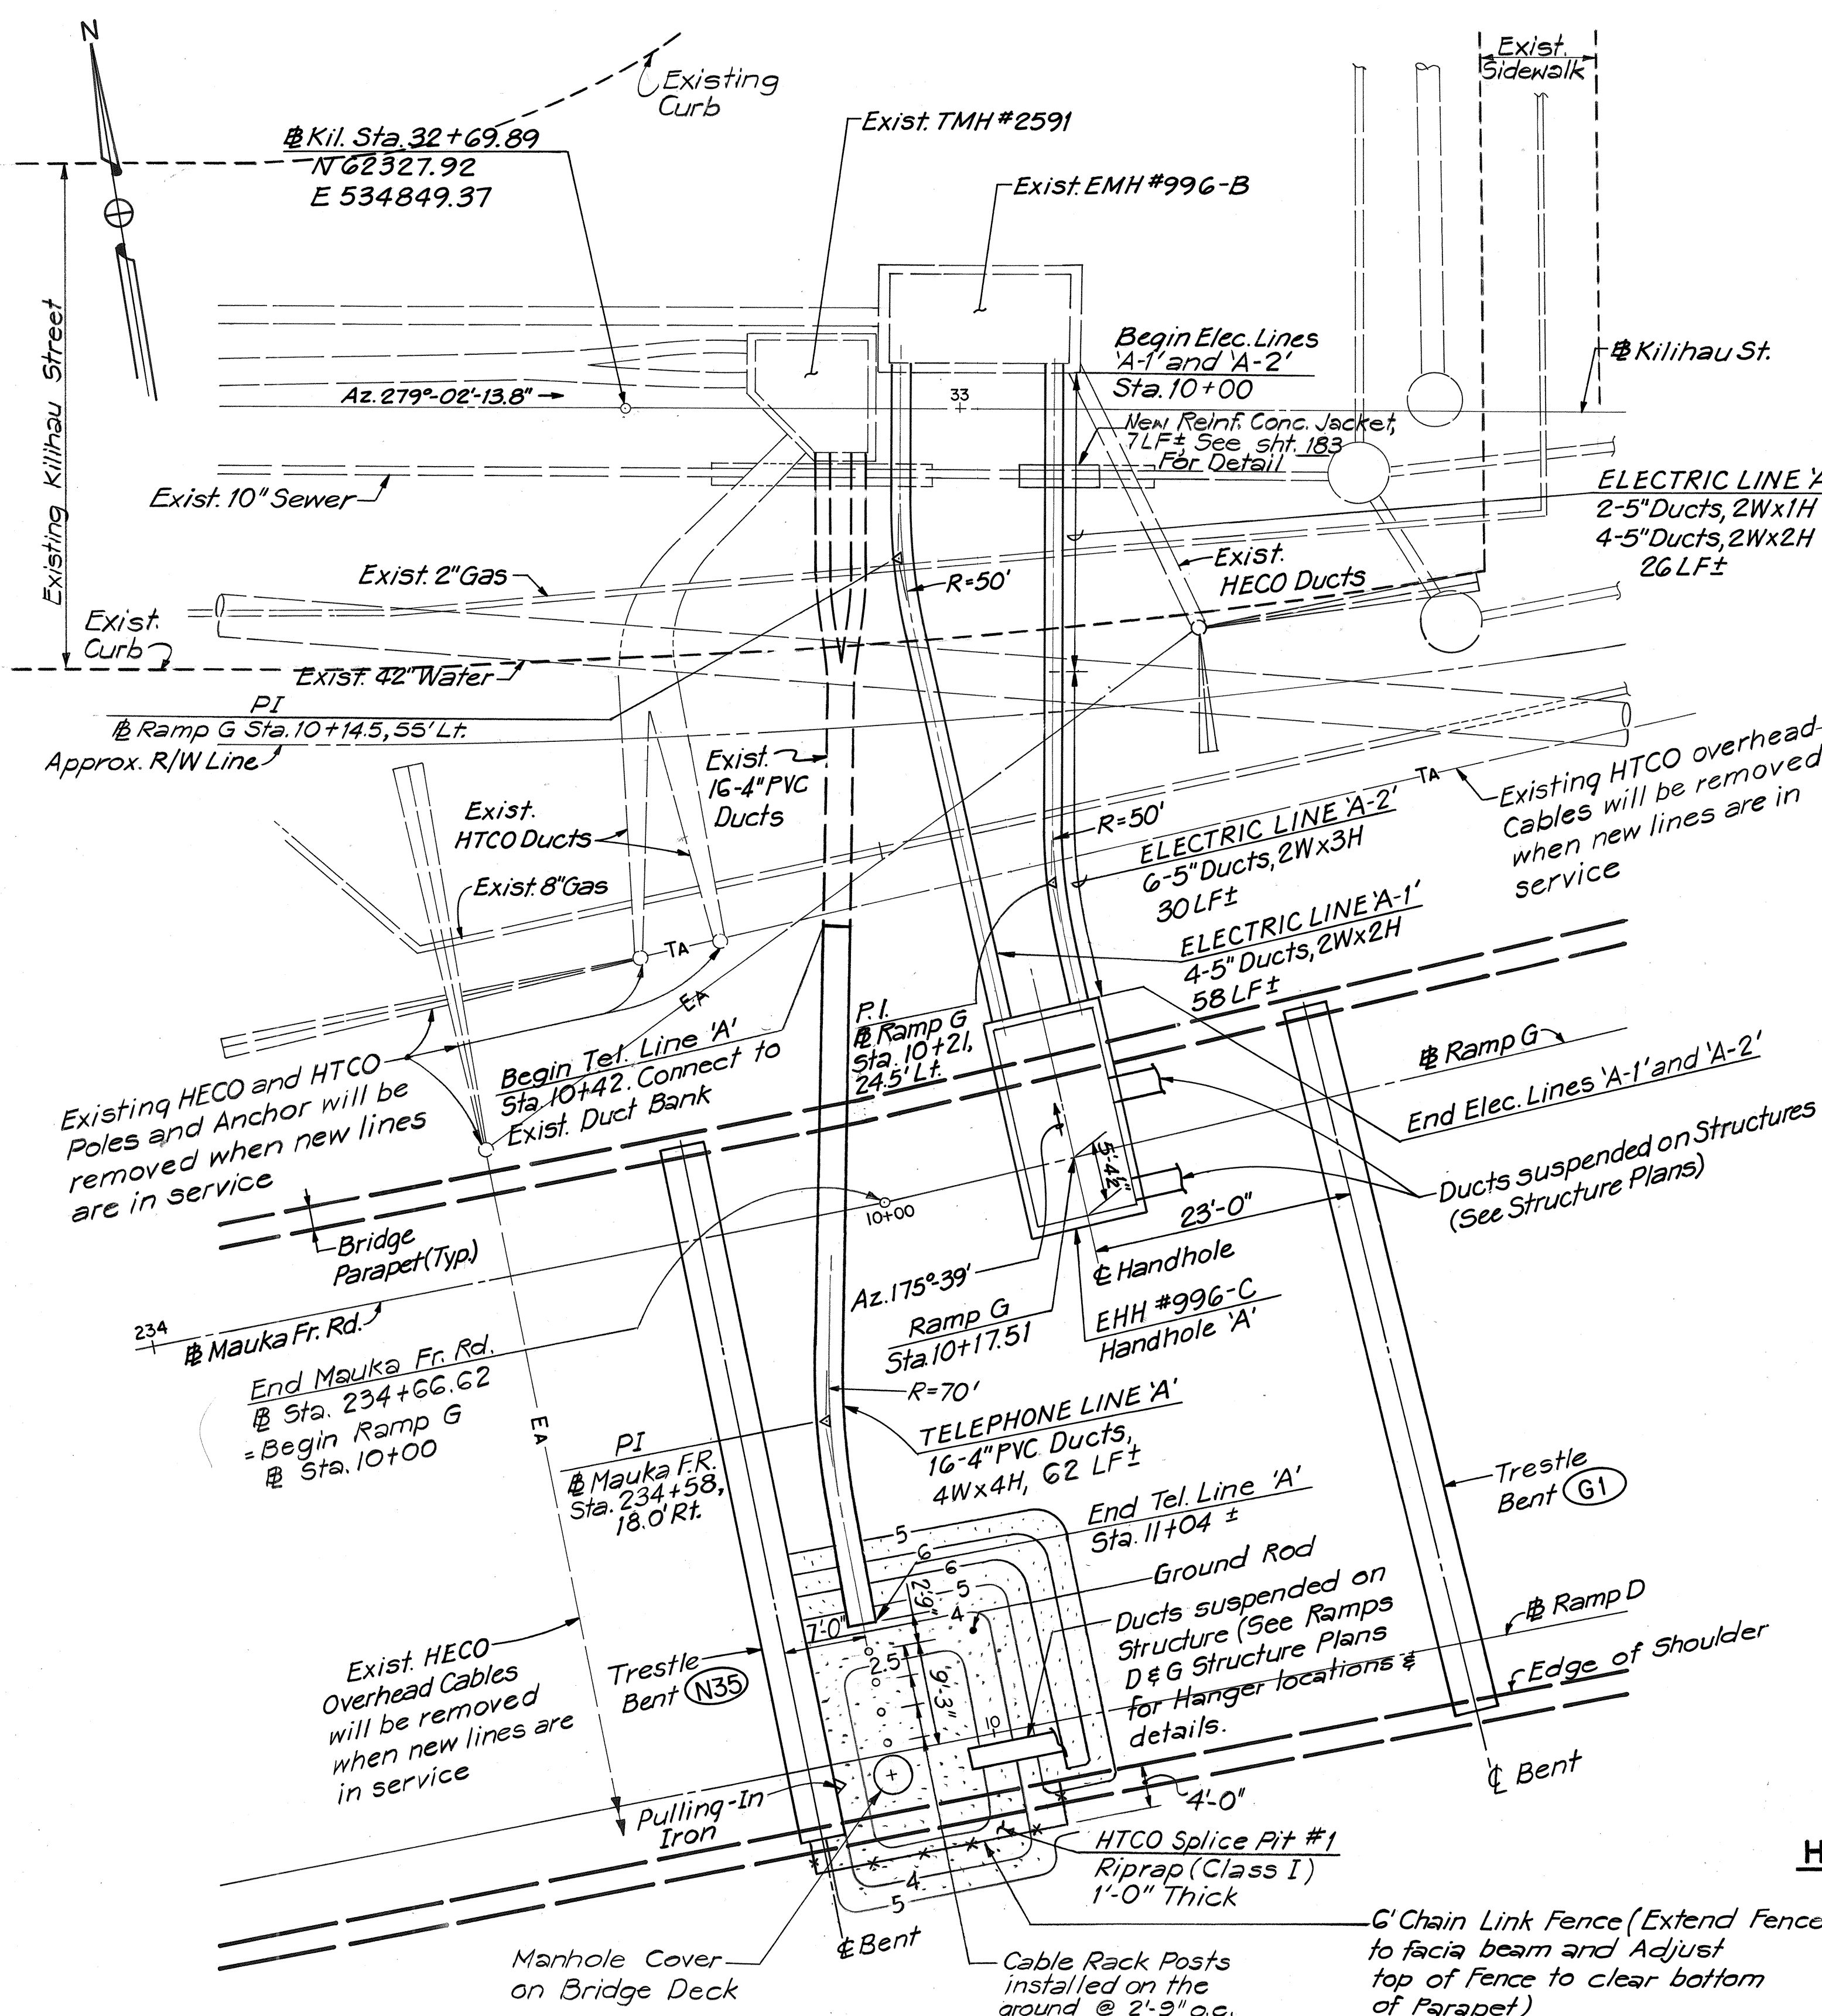


PLAN DETAIL AT HTCO SPLICE PIT #1 & EHH #996-C
SCALE: 1"=10'

NOTE: For Cable Rack Post Detail, see sheet No. 168


APPROVED:
[Signature]
HAWAIIAN ELECTRIC CO., INC.
[Signature]
HAWAIIAN TELEPHONE CO.
8/18/77
DATE
8-15-77
DATE

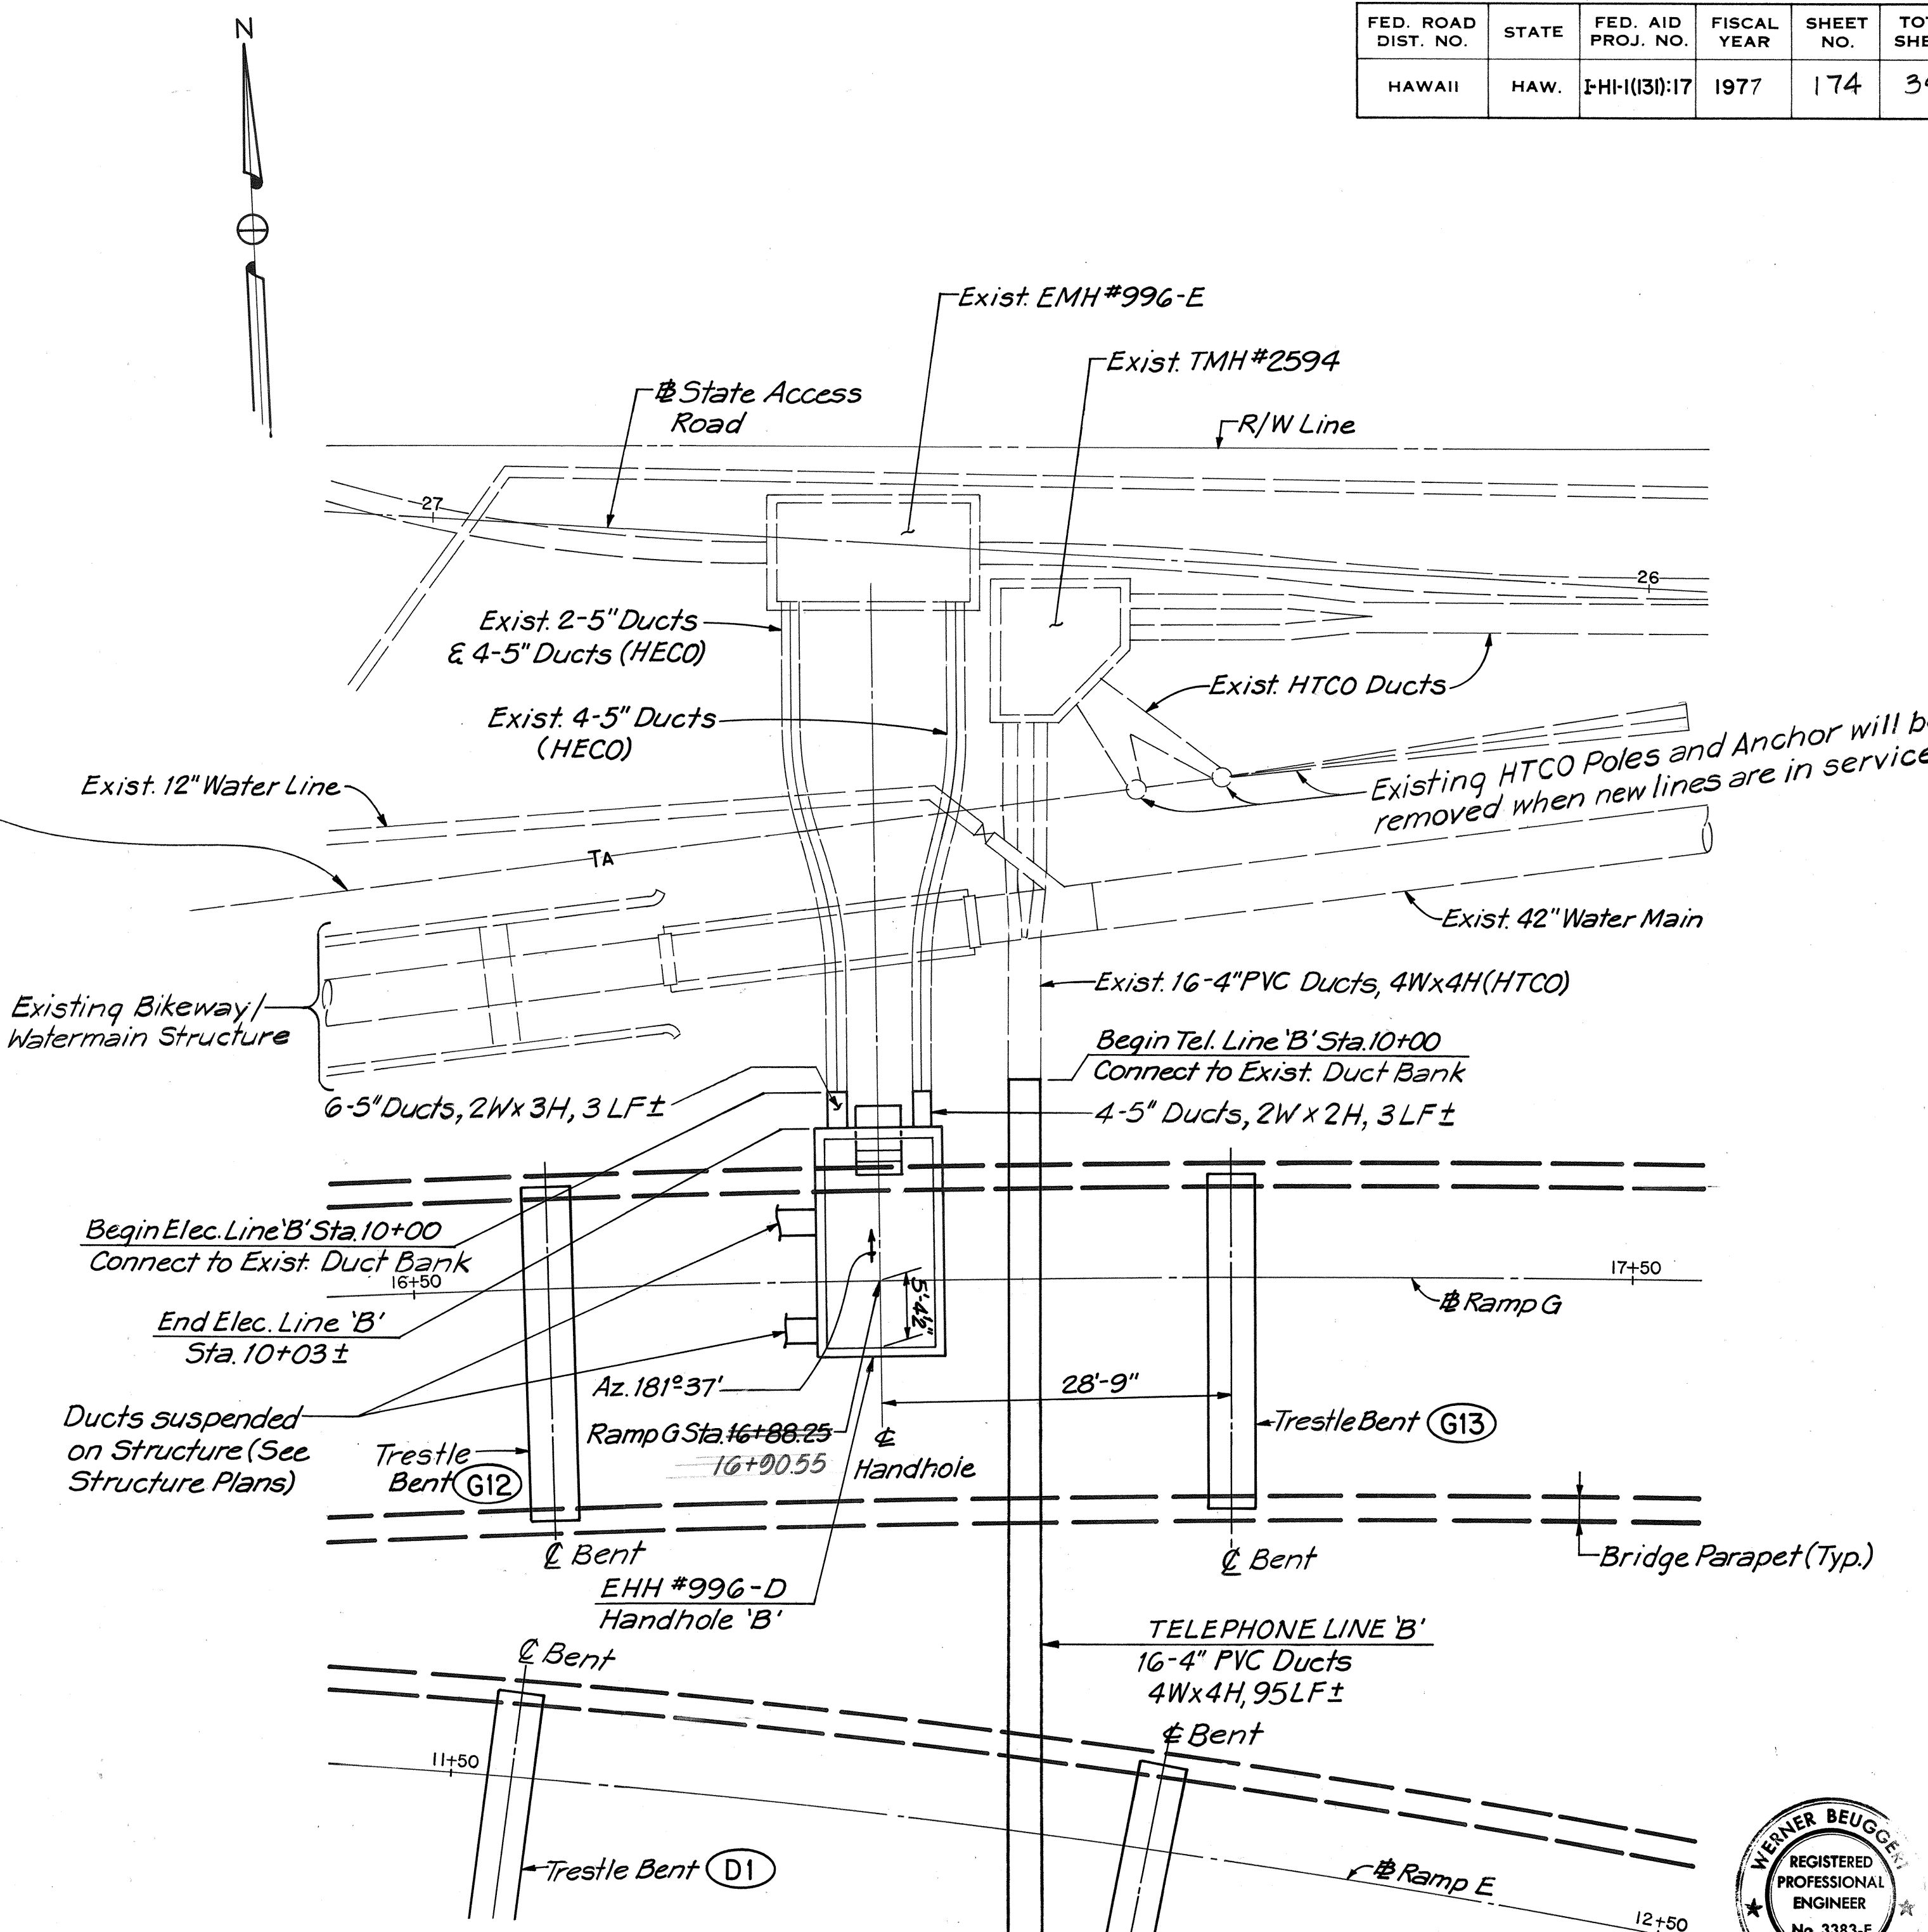

PLAN DETAIL AT
HTCO SPLICE PIT #2 & EHH #996-D
SCALE: 1"=10'




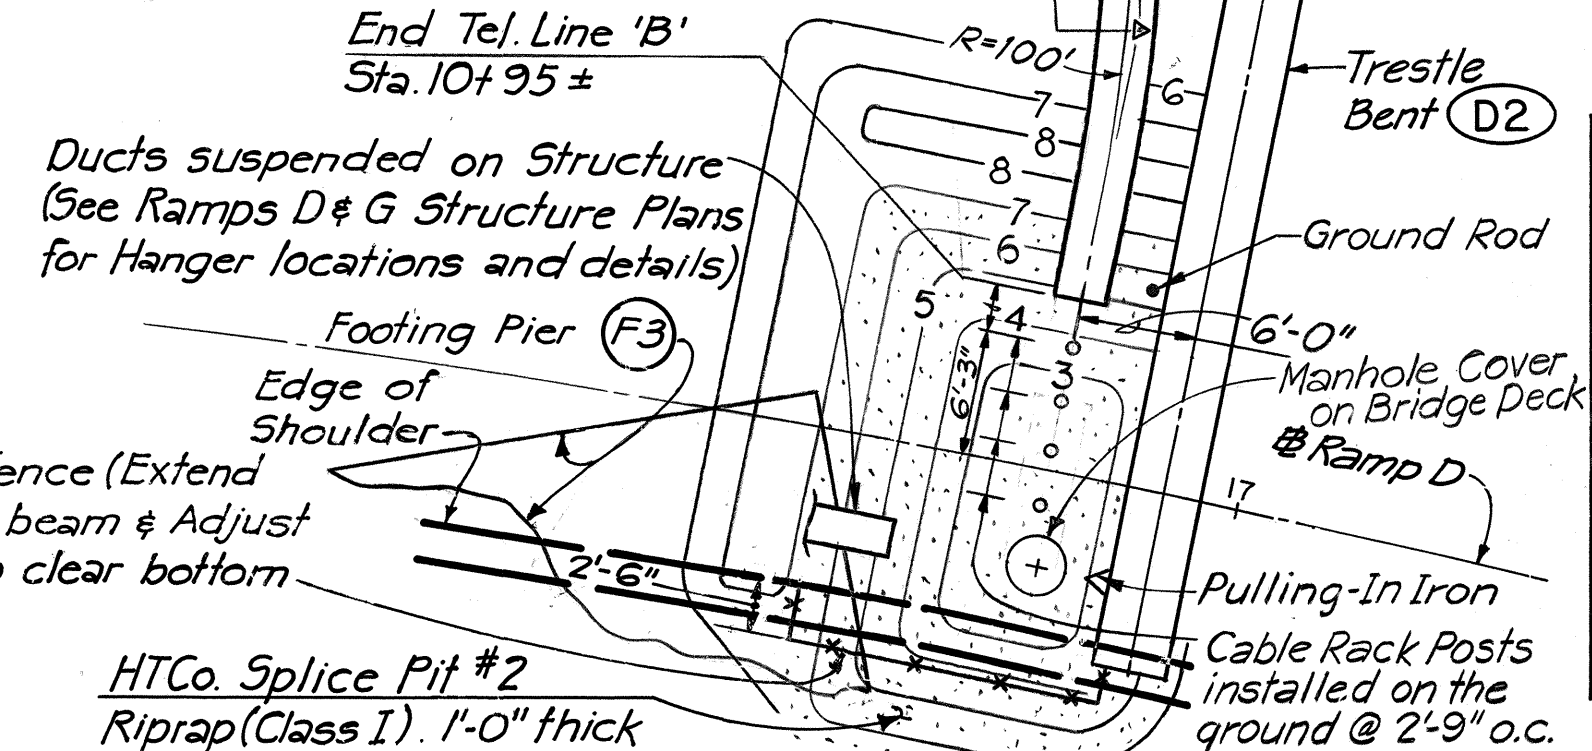


STATE OF HAWAII
DEPARTMENT OF TRANSPORTATION
HIGHWAYS DIVISION
UTILITIES PLAN DETAILS
TELEPHONE LINES 'A' & 'B'
ELECTRIC LINES 'A-1', 'A-2' & 'B'
INTERSTATE ROUTE H-1
PROJECT NO. I-H1-1(131):17
SCALE: AS SHOWN
DATE: AUG. 31, 1977
SHEET NO. U-2 OF U-23 SHEETS

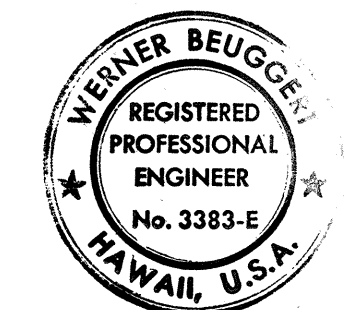

THIS WORK WAS PREPARED BY ME
OR UNDER MY SUPERVISION.
[Signature]

FED. ROAD DIST. NO.	STATE	FED. AID PROJ. NO.	FISCAL YEAR	SHEET NO.	TOTAL SHEETS
HAWAII	HAW.	I-HI-1(131):17	1977	175	394

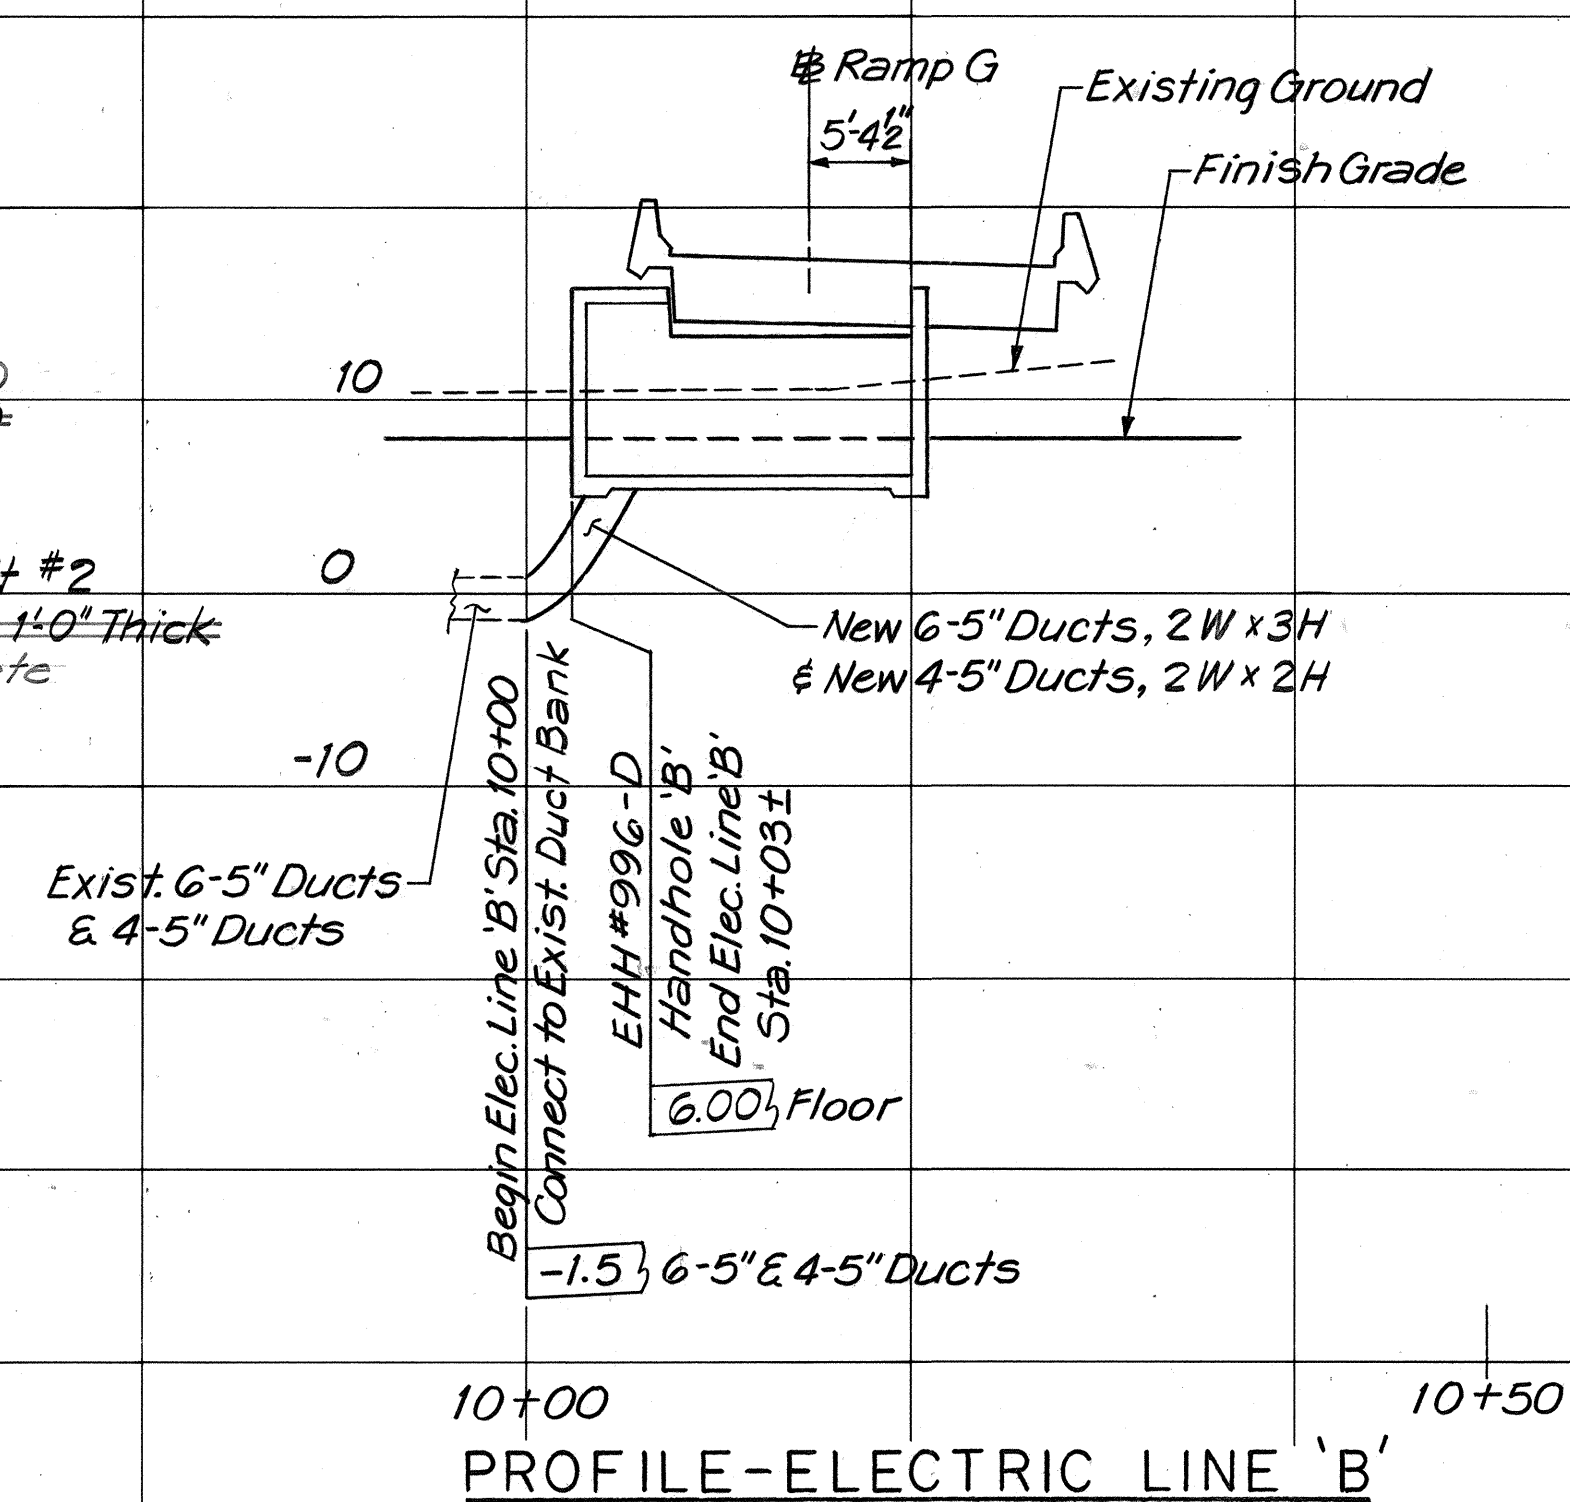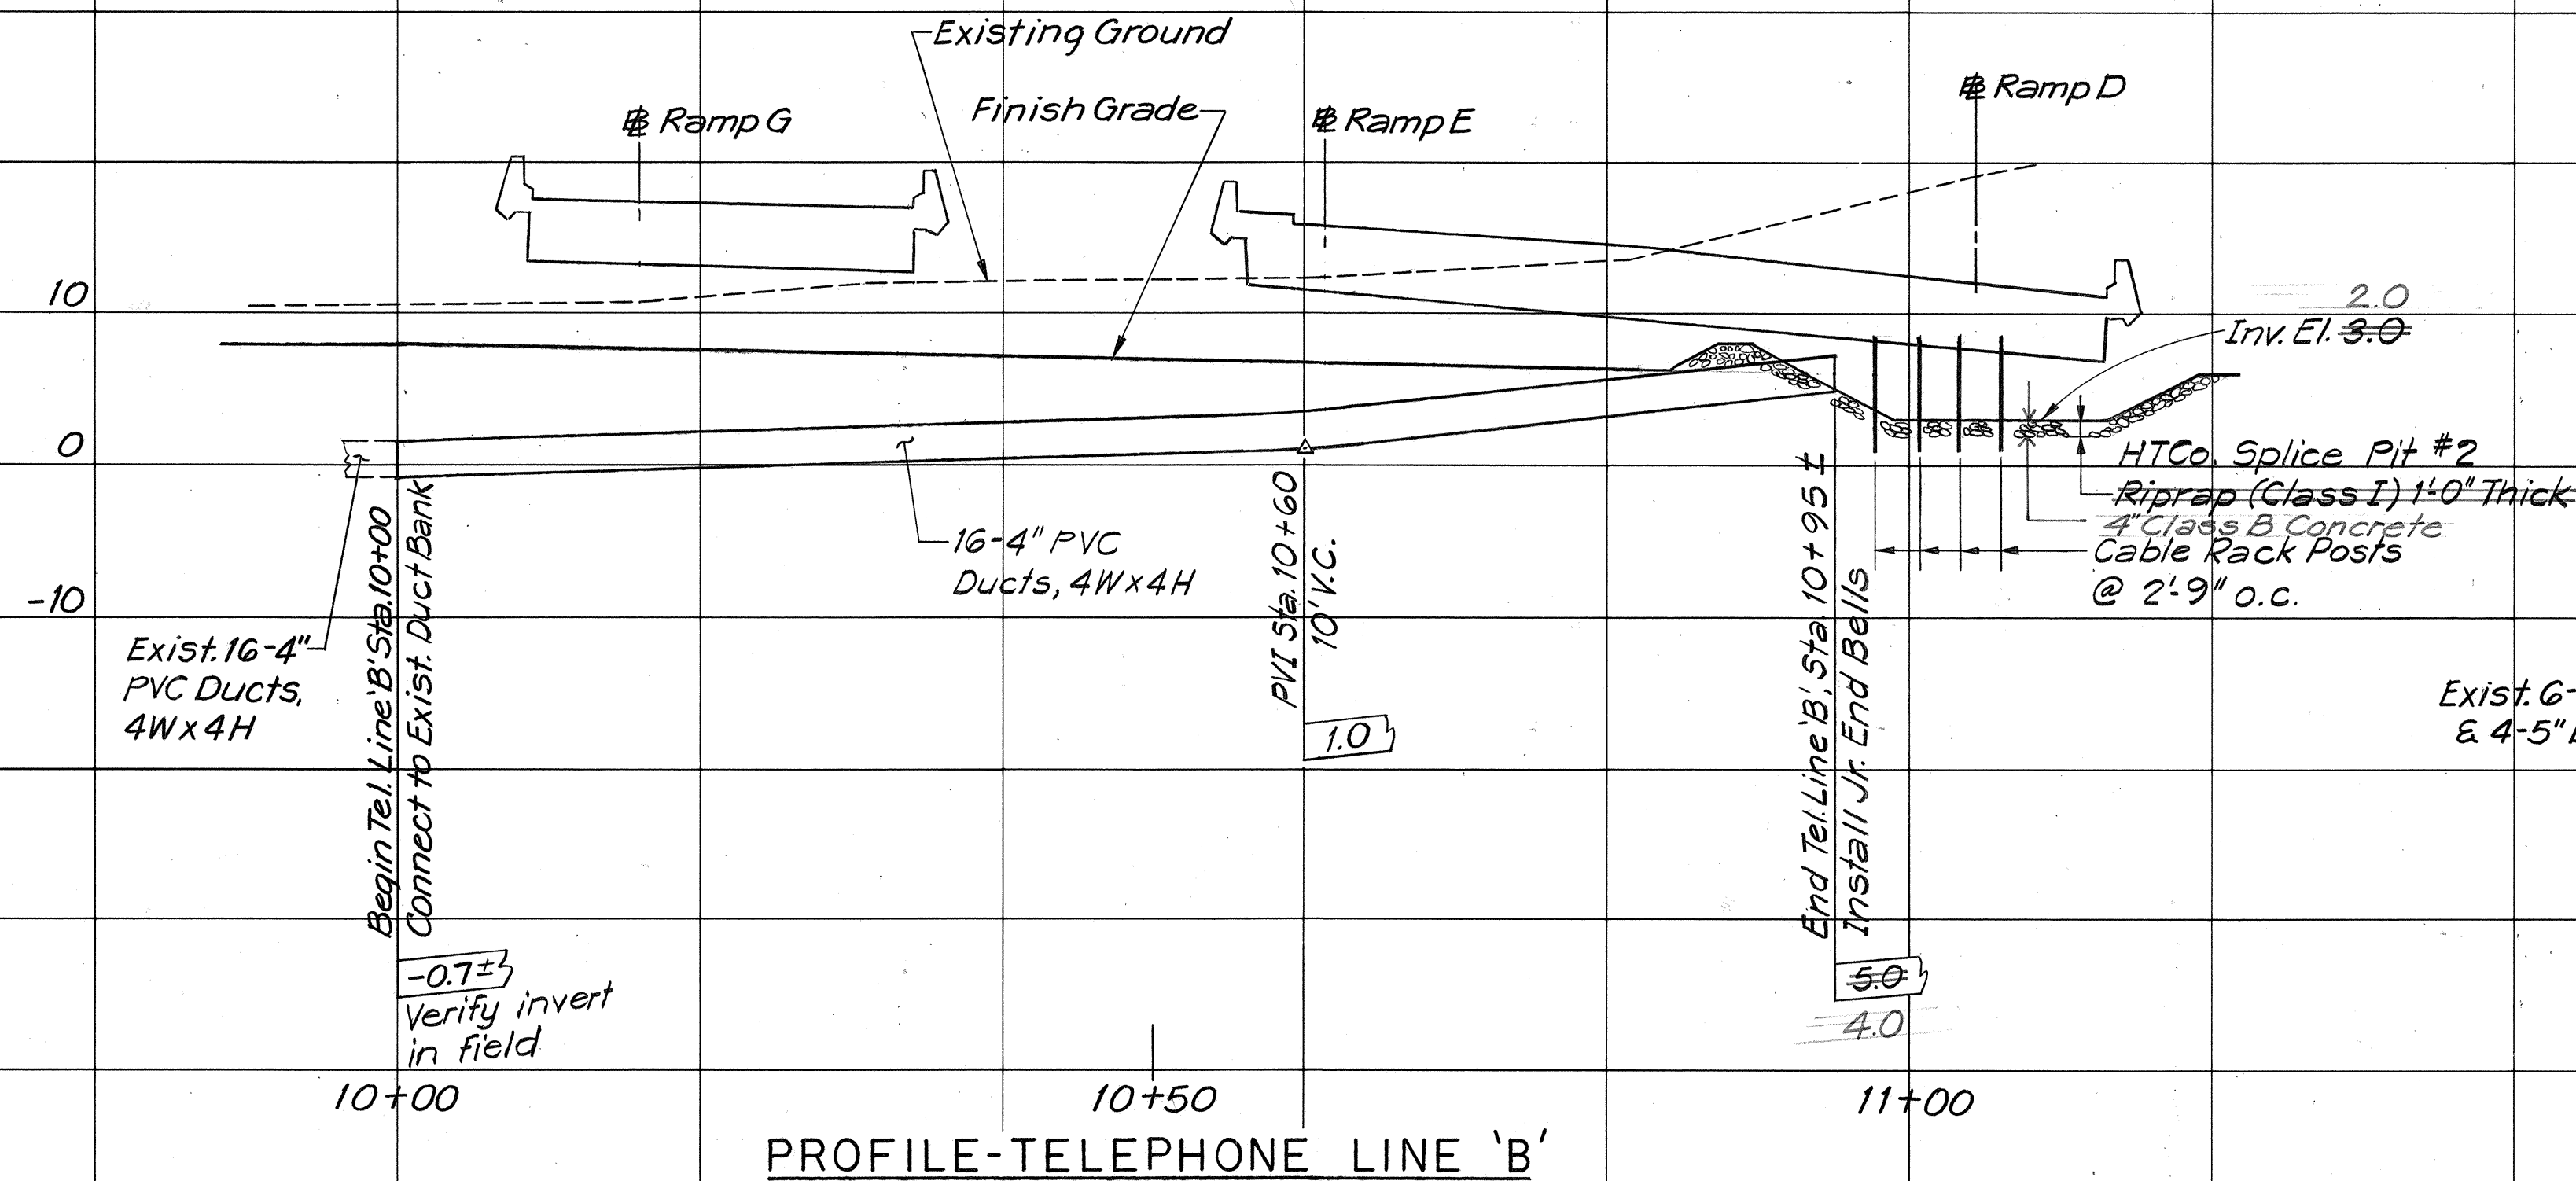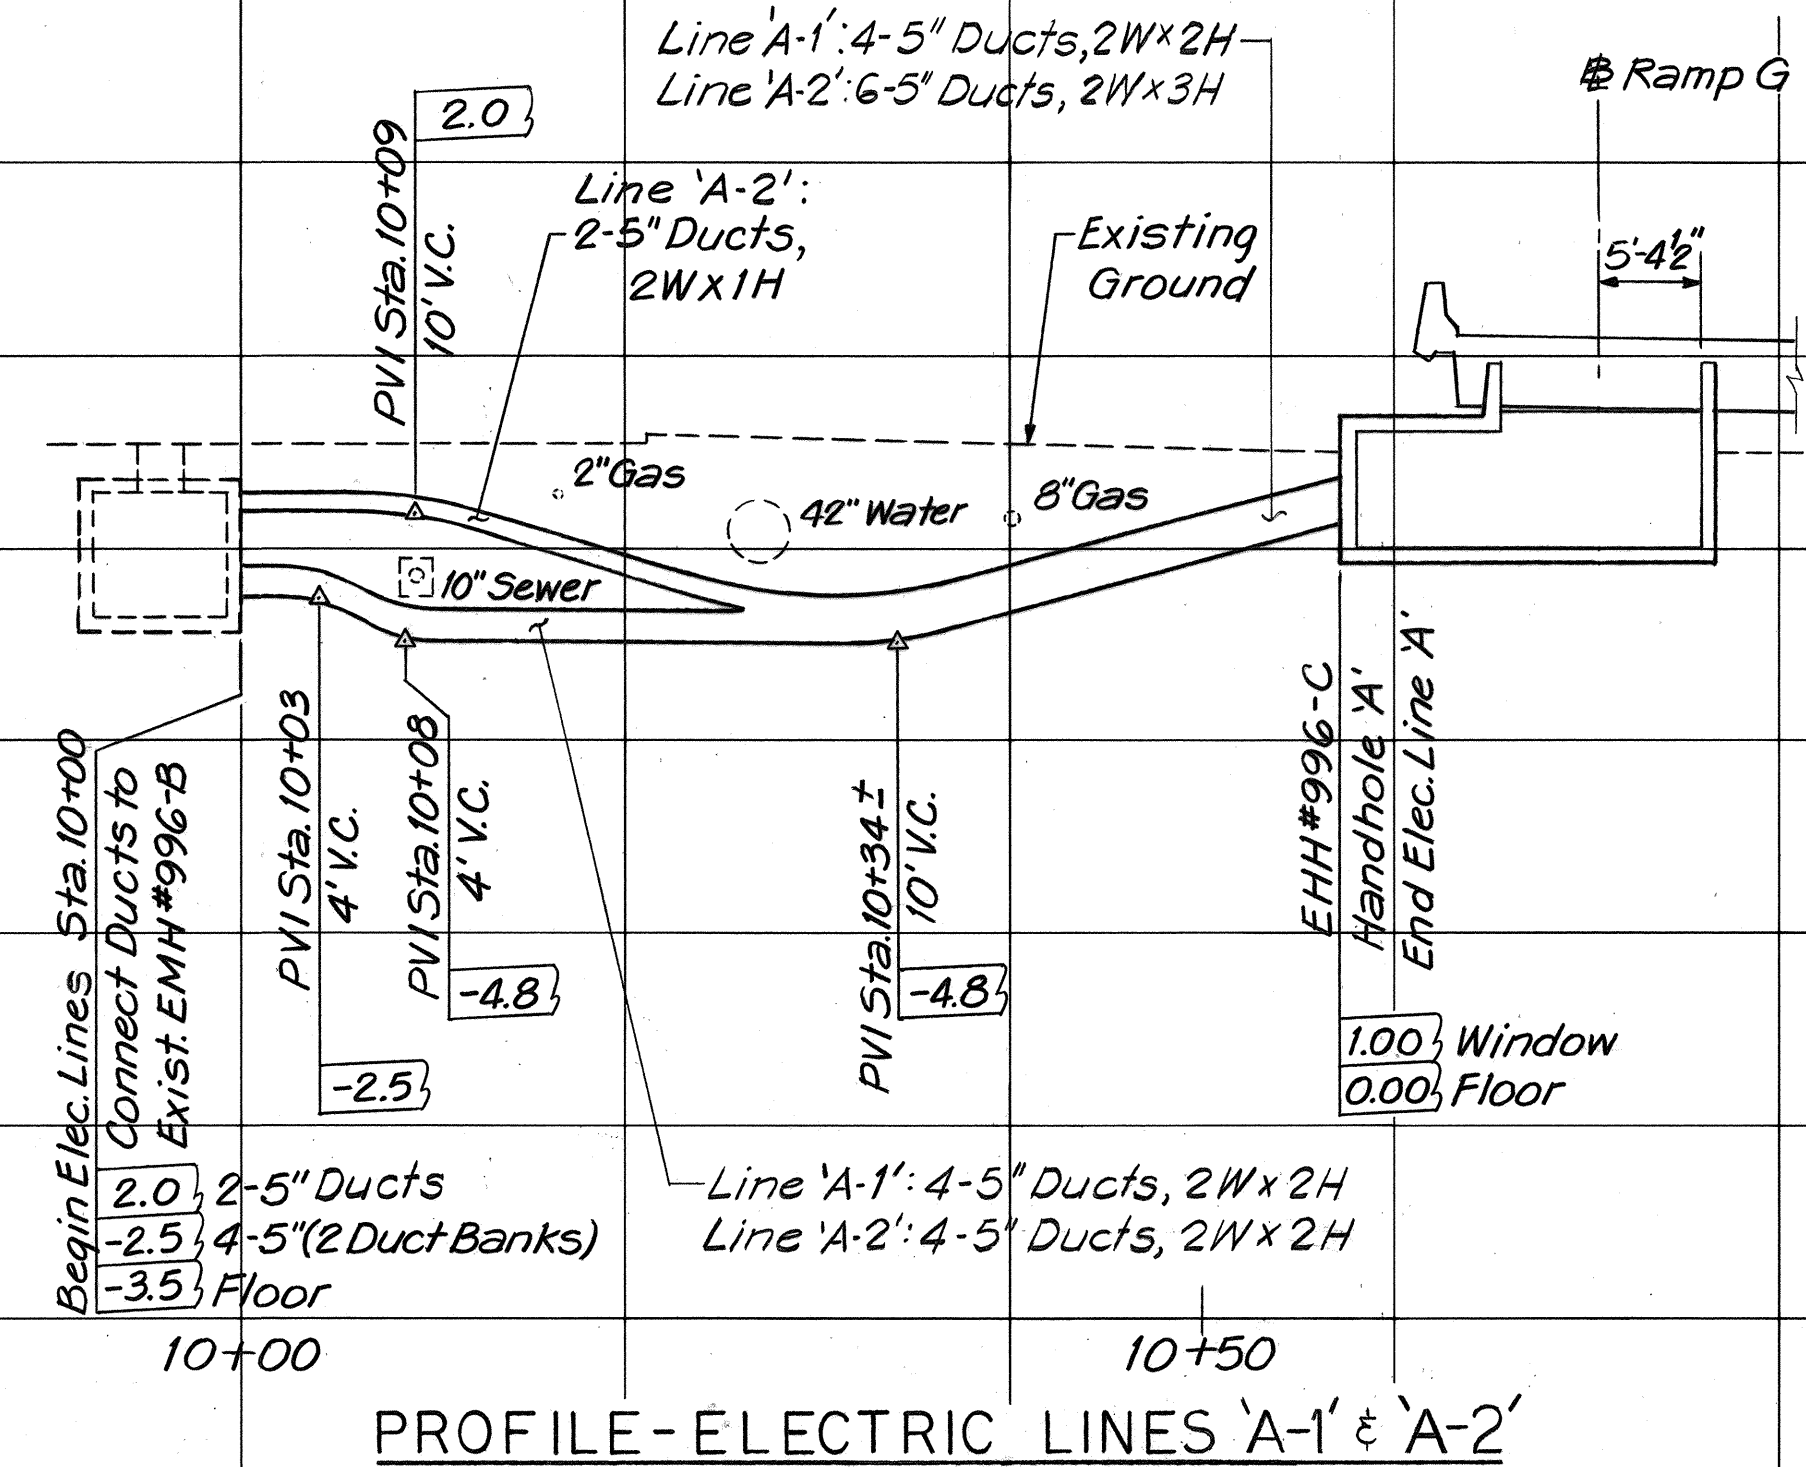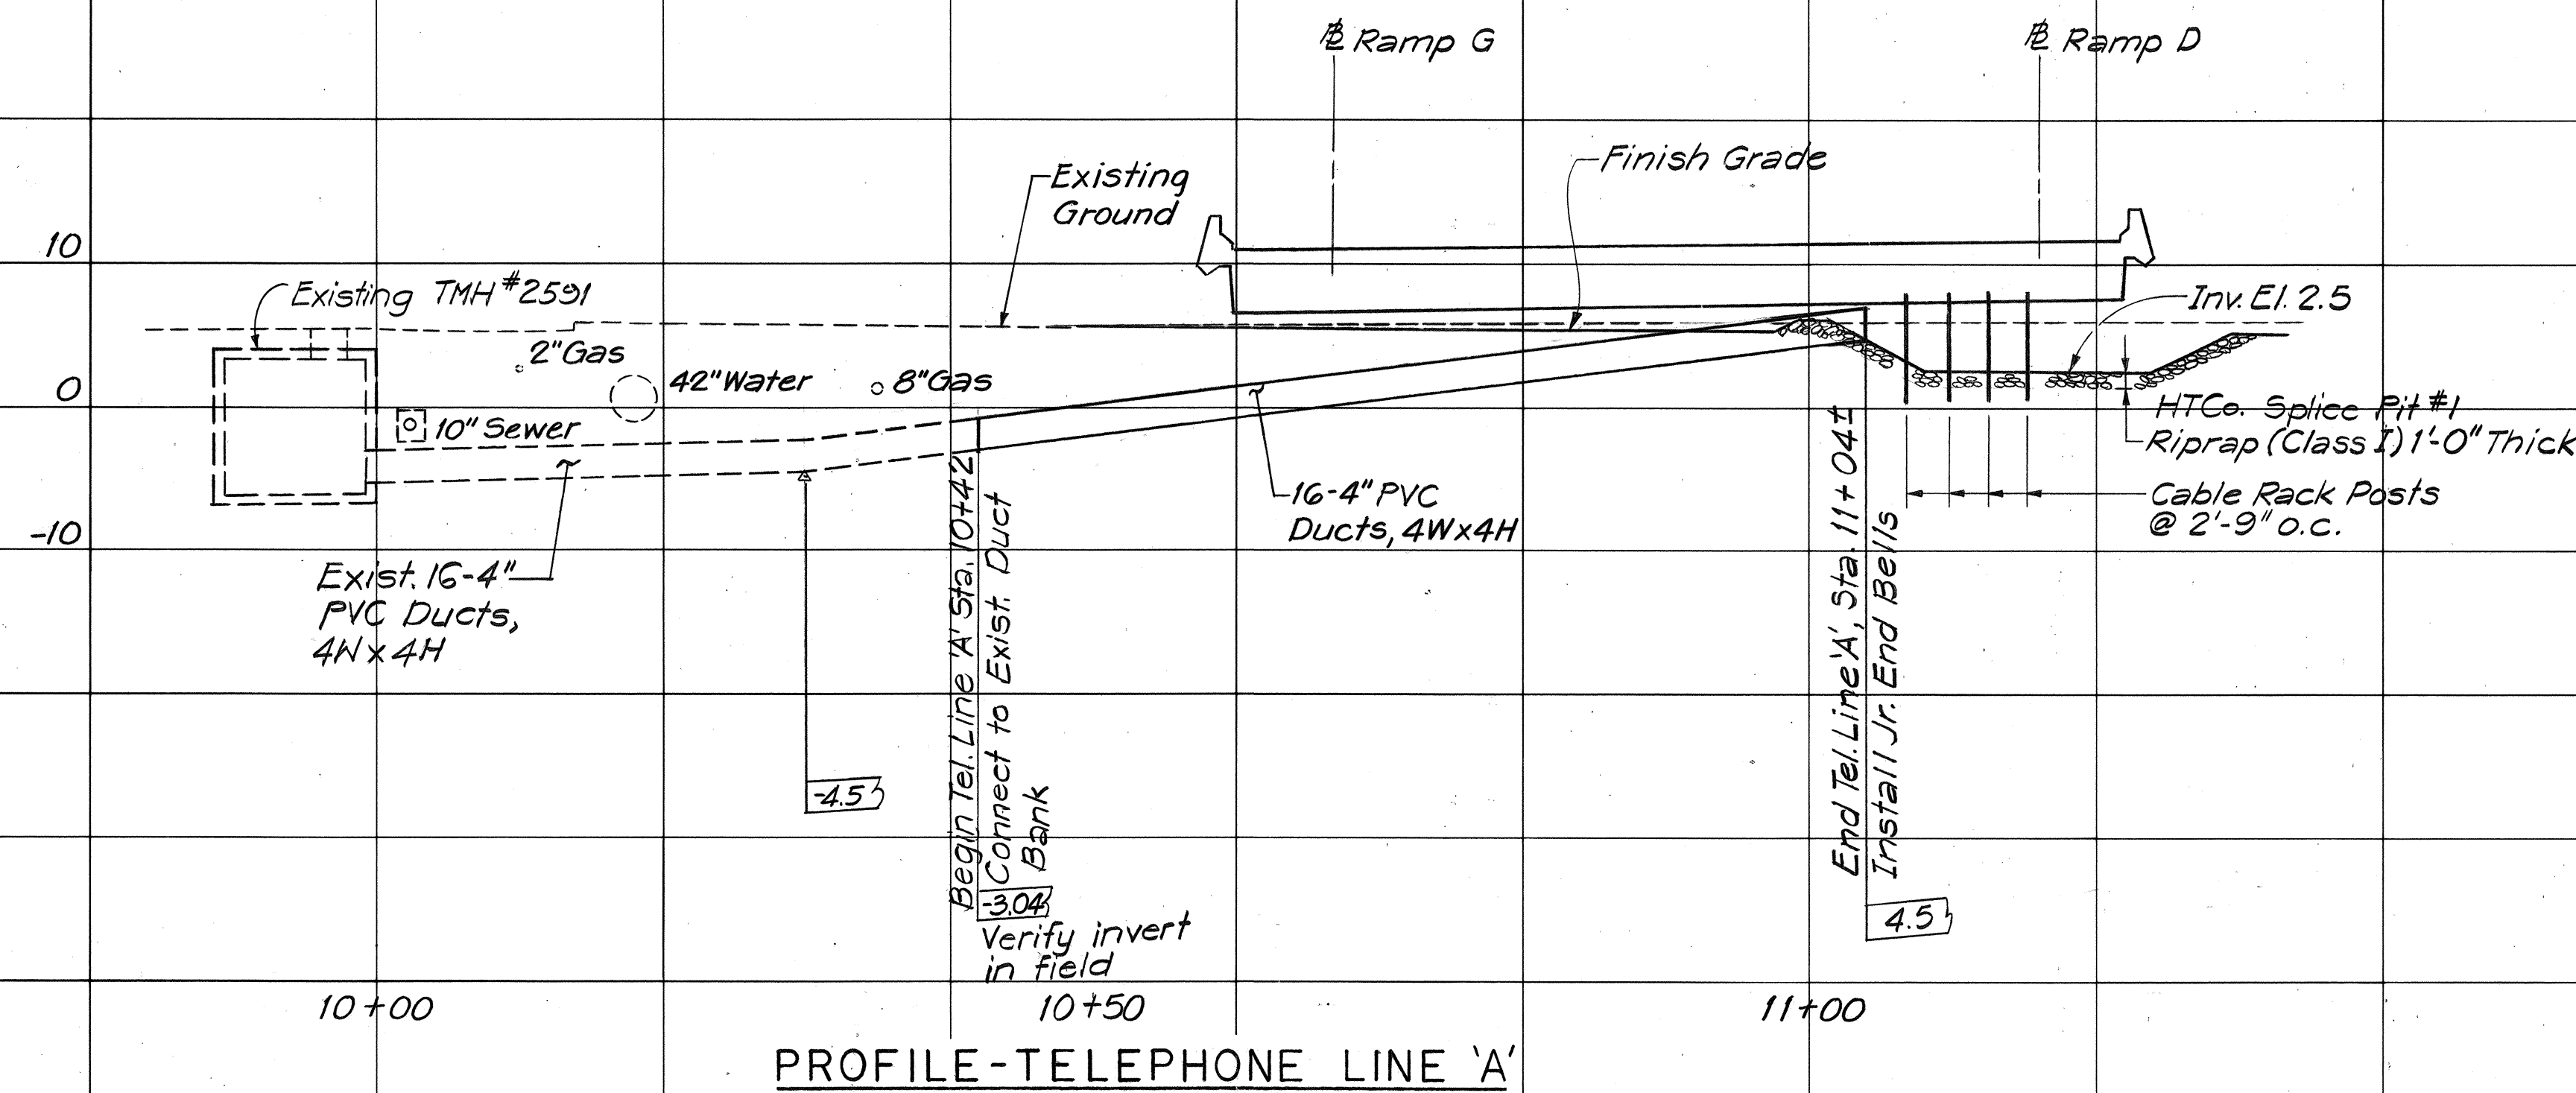


ORIGINAL PLAN	DATE
SURVEYED BY	
DRAWN BY	
CHECKED BY	
NOTED BY	
NO.	

APPROVED:

B. Chandra
HAWAIIAN TELEPHONE CO.
B. Karim
HAWAIIAN ELECTRIC CO., INC.


8-15-77
DATE
8/10/77
DATE

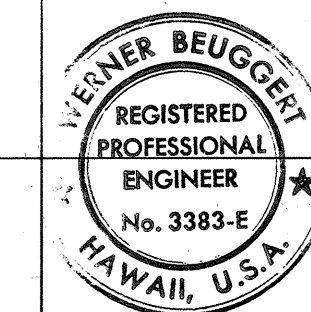


THIS WORK WAS PREPARED BY ME
OR UNDER MY SUPERVISION.
Werner Beugnot

STATE OF HAWAII
DEPARTMENT OF TRANSPORTATION
HIGHWAYS DIVISION
UTILITIES PROFILES
TELEPHONE LINES 'A' & 'B'
ELECTRIC LINES 'A-1', 'A-2' & 'B'
INTERSTATE ROUTE H-1
PROJECT NO. I-HI-1(131):17
SCALE: HORIZ.: 1"=10'
VERTICAL: 1"=10'
DATE: AUG. 31, 1977
SHEET No. 0-3 OF 0-23 SHEETS


FED. ROAD DIST. NO.	STATE	FED. AID PROJ. NO.	FISCAL YEAR	SHEET NO.	TOTAL SHEETS
HAWAII	HAW.	I-H1-1(131):17	1977	176	394

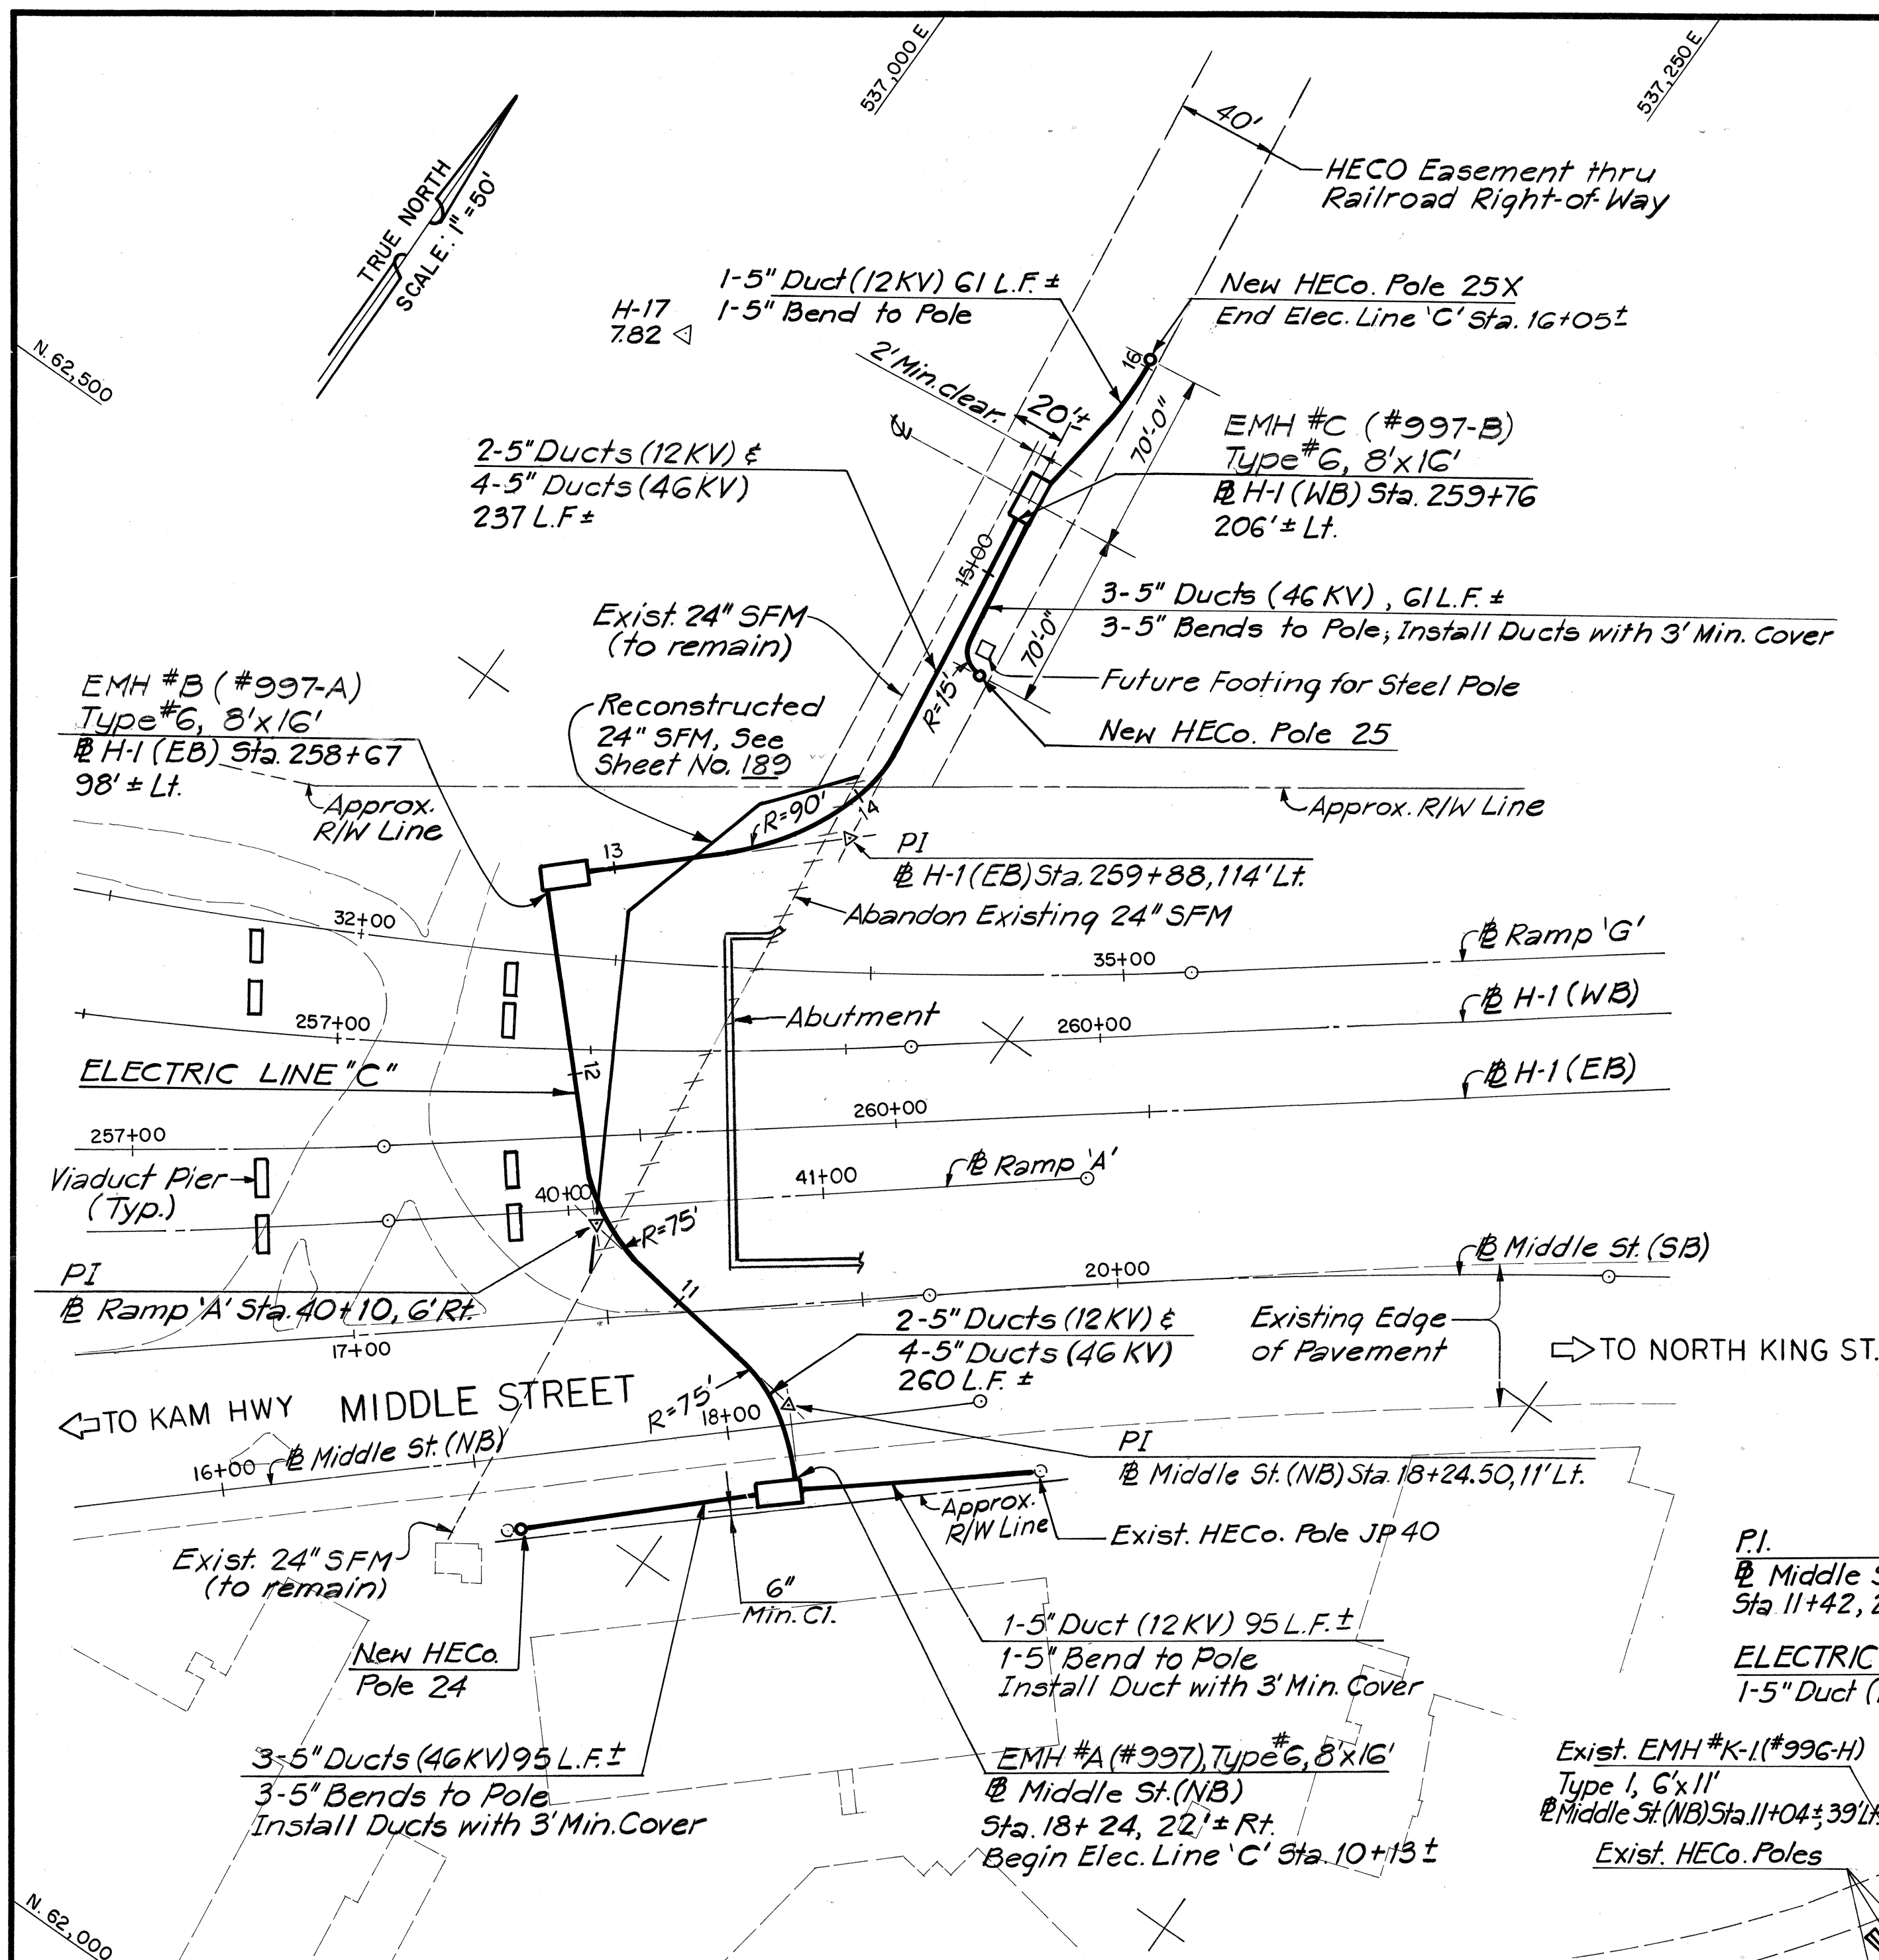


PLAN - ELECTRIC LINE 'C'
SCALE: 1" = 50'

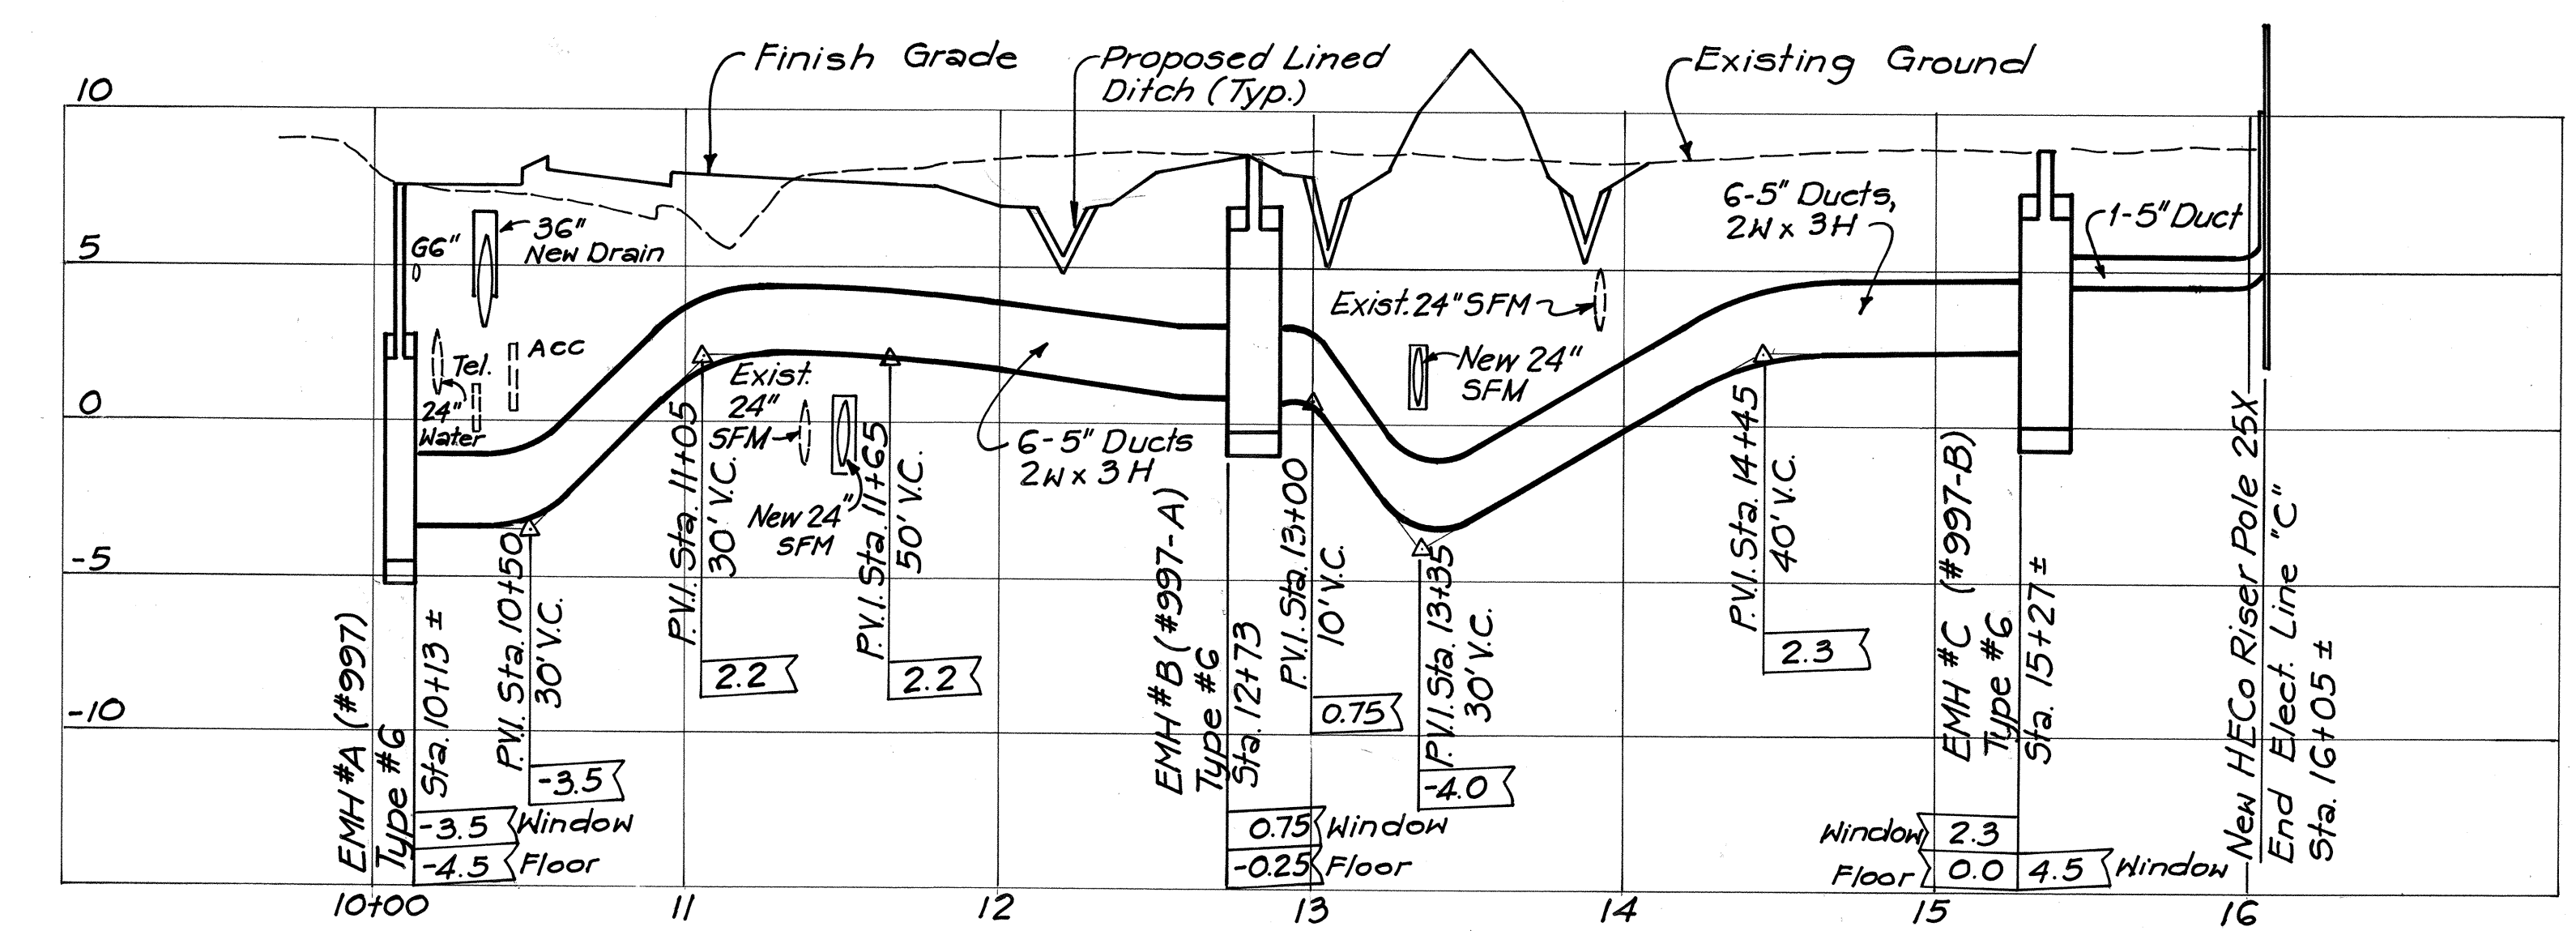

PROFILE - ELECTRIC LINE 'C'
SCALE: HORIZ. 1" = 50'
VERT. 1" = 5'

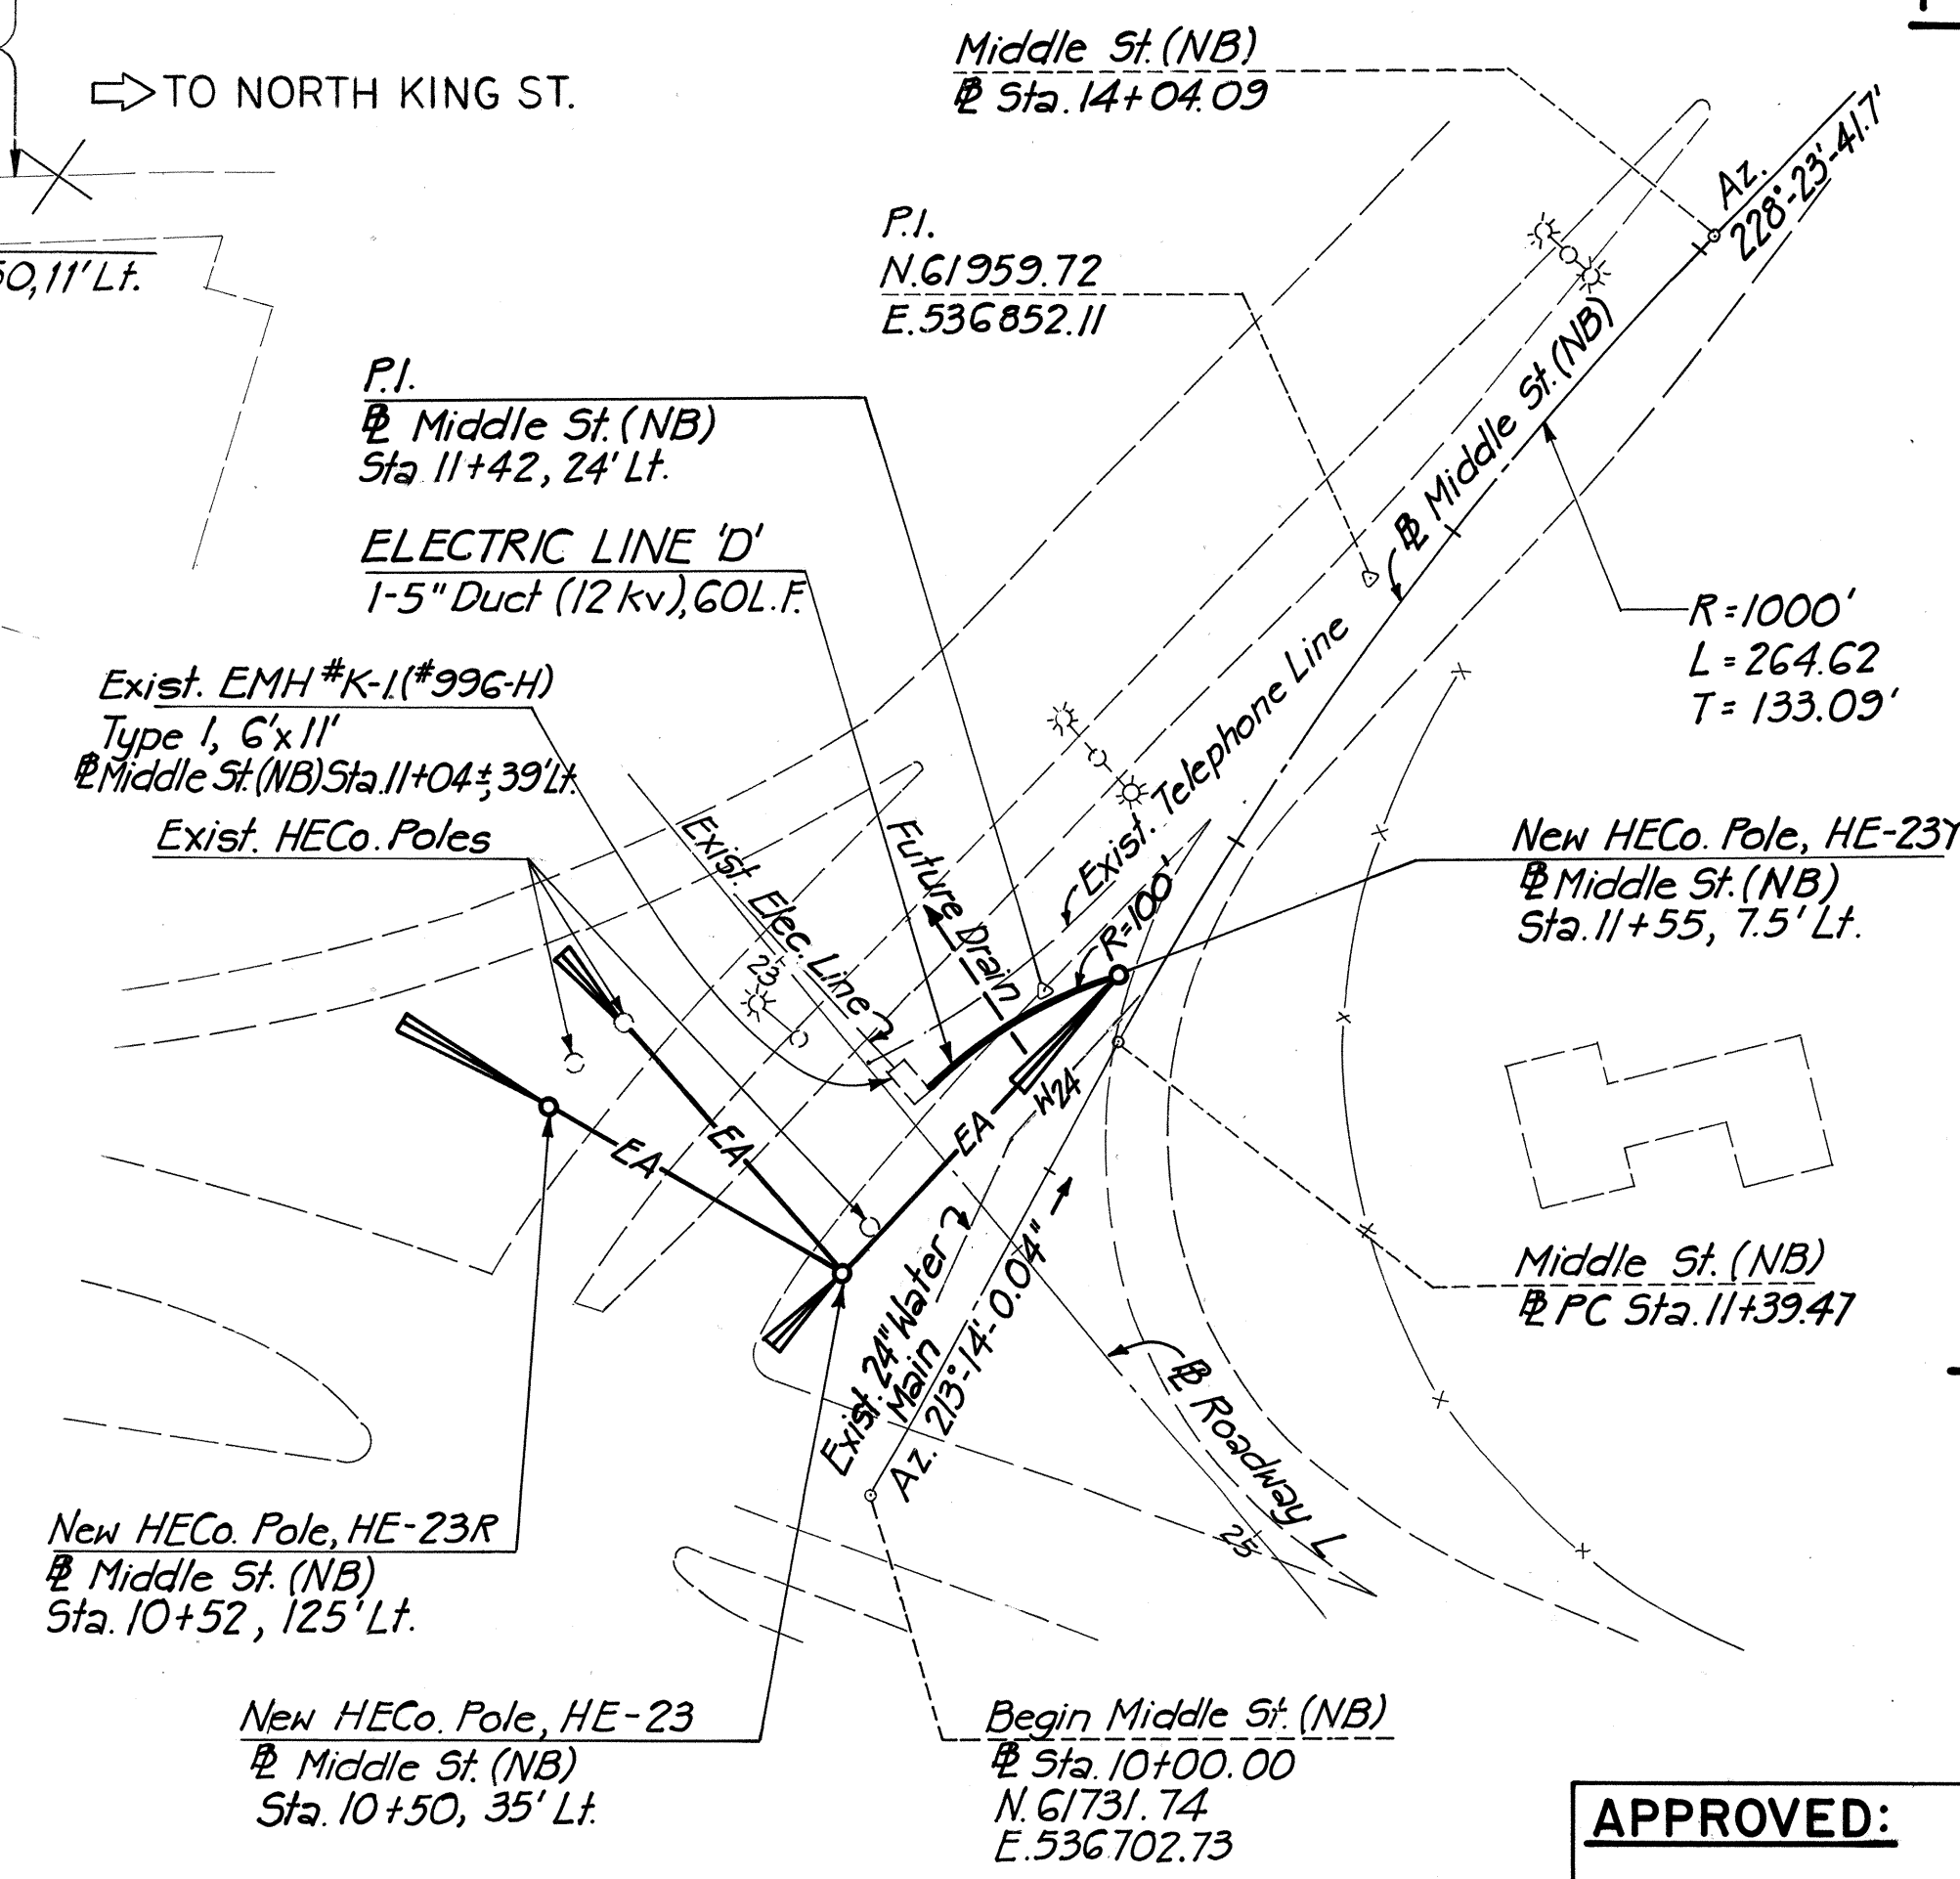

PLAN - ELECTRIC LINE 'D'
SCALE: 1" = 50'

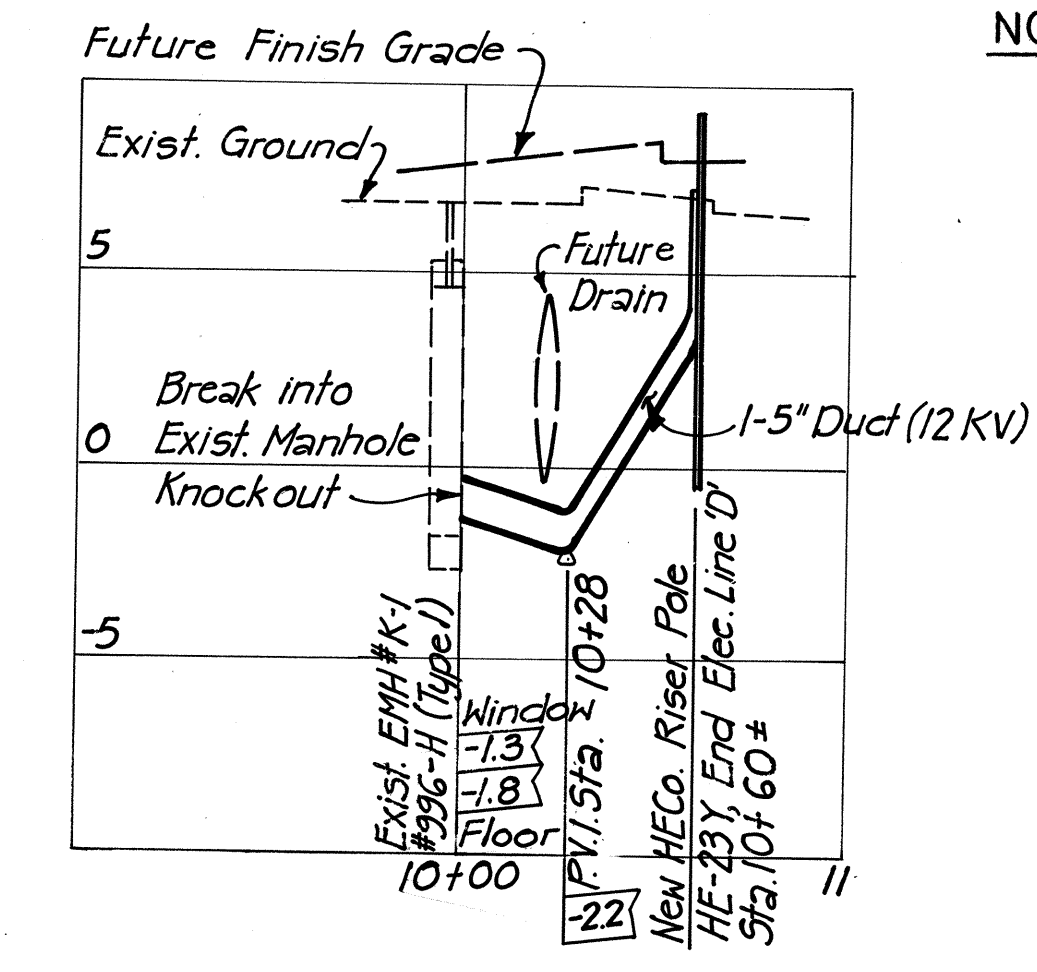


PROFILE - ELECTRIC LINE 'D'
SCALE: HORIZ. 1" = 50'
VERT. 1" = 5'

- NOTES:**
- Offsets shown are measured from the baseline to the outer face of the man-hole wall.
 - For existing utility facilities see Sheet No. 193 & 194

DATE	8/10/77
SURVEY PLOTTED BY	W. K. K.
DRAWN BY	W. K. K.
CHECKED BY	W. K. K.
ORIGINAL PLAN	NO.
NOTE BOOK	NO.

APPROVED:
HAWAIIAN ELECTRIC CO., INC.
DATE: 8/10/77

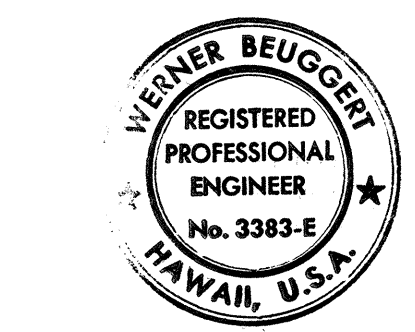


STATE OF HAWAII
DEPARTMENT OF TRANSPORTATION
HIGHWAYS DIVISION


**PLAN AND PROFILE OF
ELECTRIC LINE 'C' & 'D'**

INTERSTATE ROUTE H-1
PROJECT NO. I-H1-1(131):17
SCALE: AS SHOWN DATE: AUG. 31, 1977
SHEET NO. U-4 OF U-23 SHEETS


FED. ROAD DIST. NO.	STATE	FED. AID PROJ. NO.	FISCAL YEAR	SHEET NO.	TOTAL SHEETS
HAWAII	HAW.	HI-1(131):17	1977	177	394

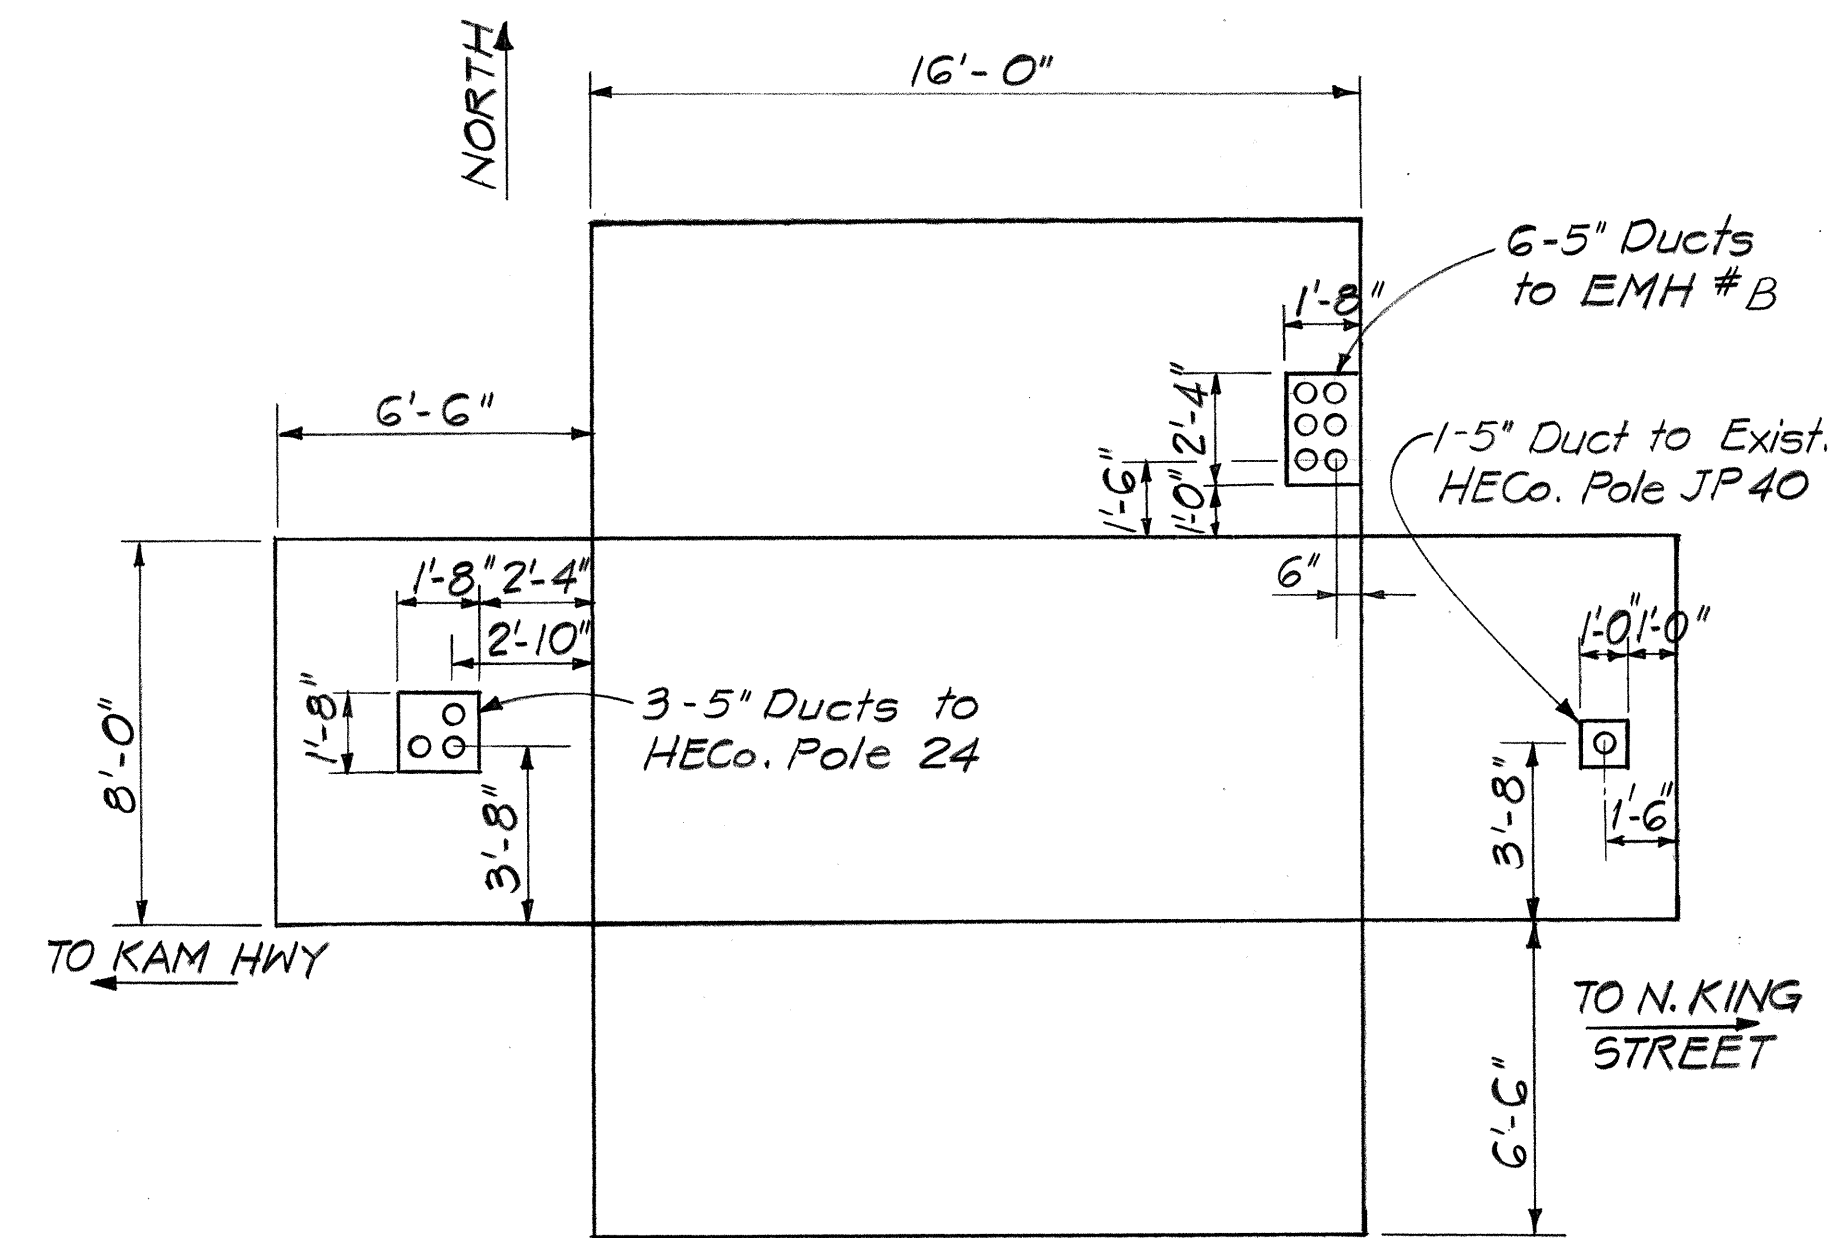


EMH #A, TYPE #6
(#997)

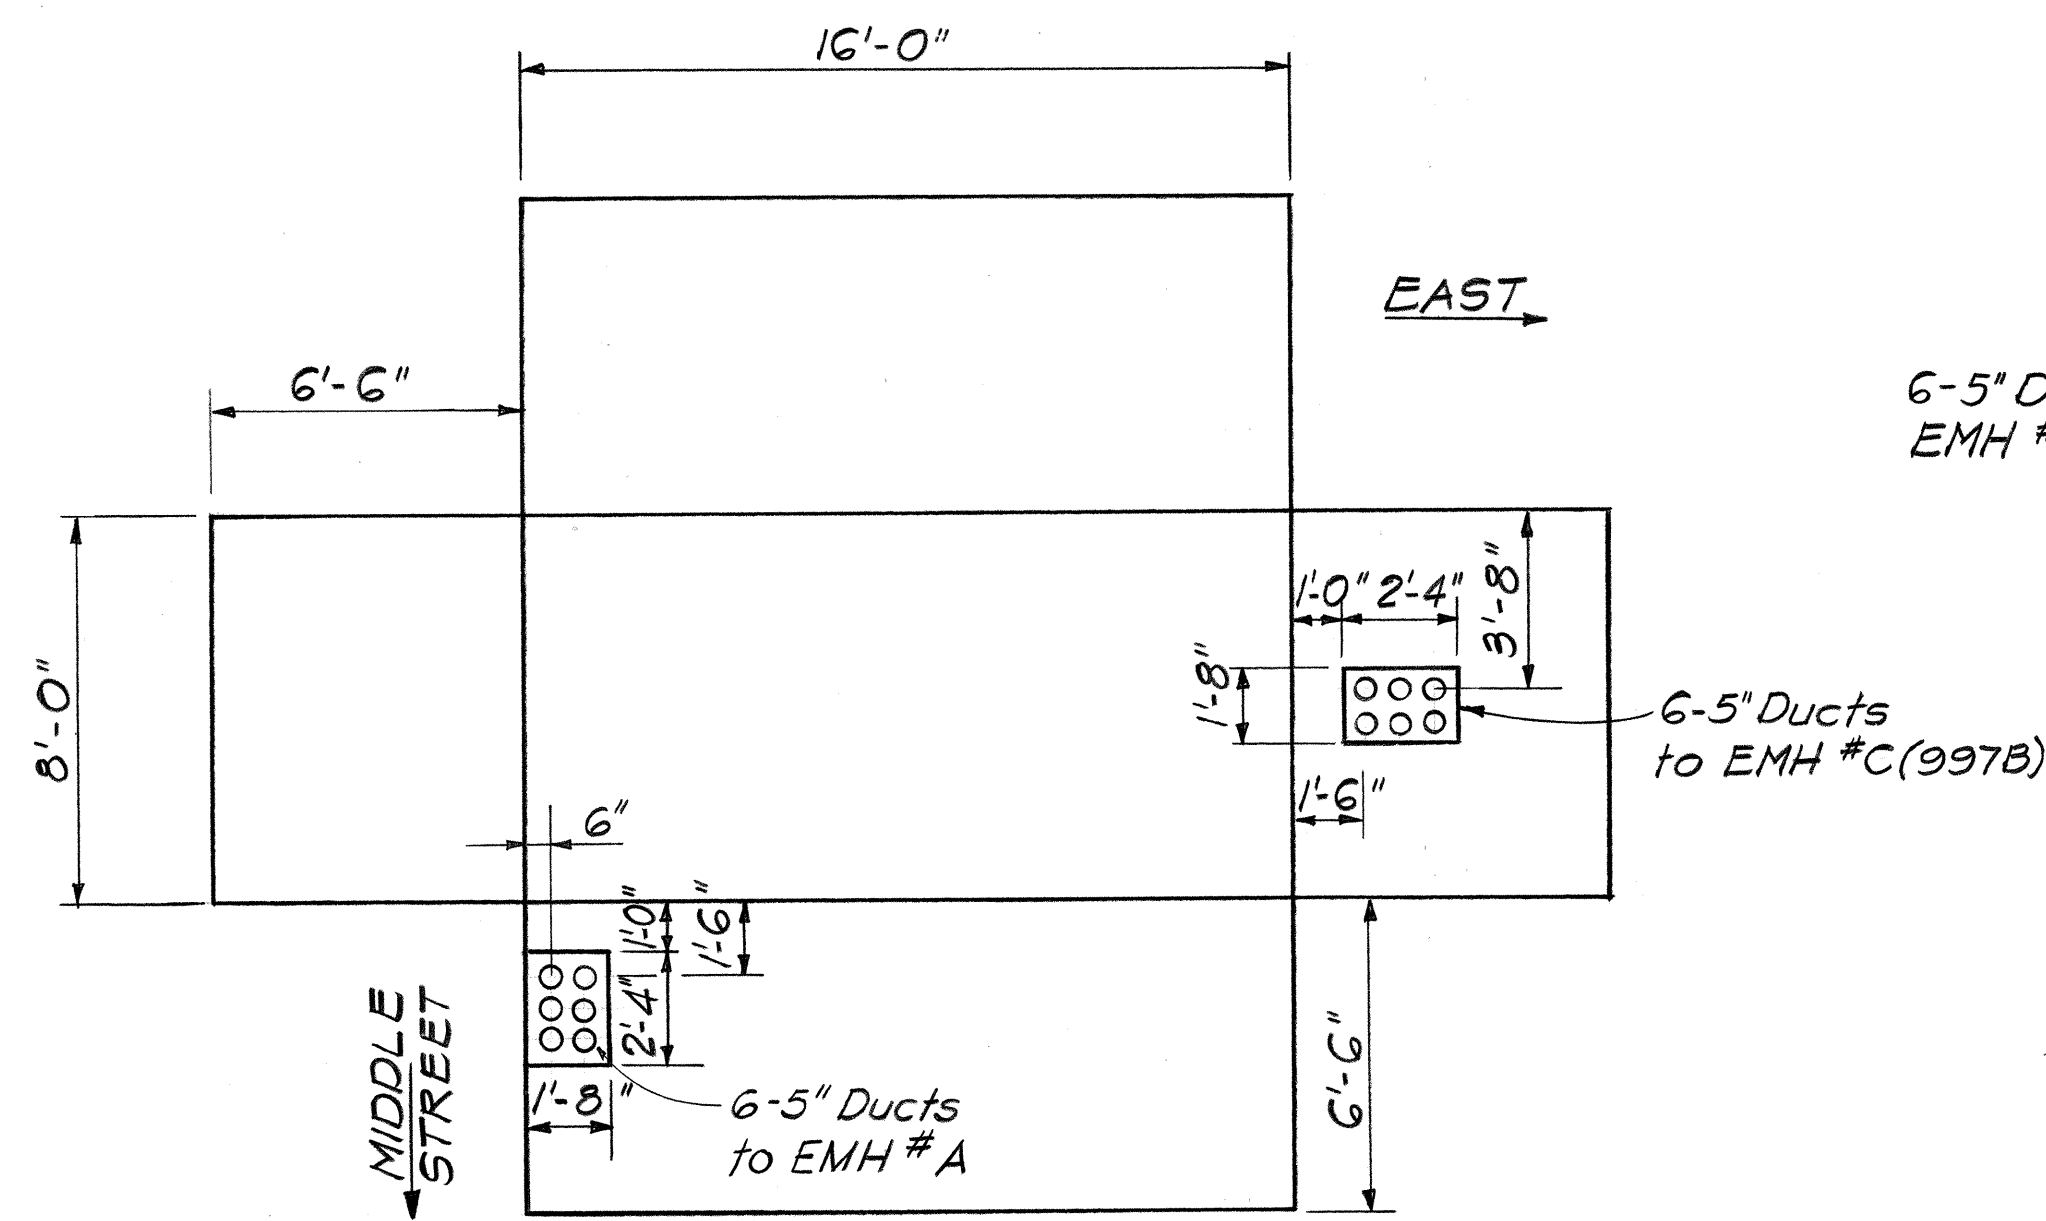


EMH #B, TYPE #6
(#997-A)

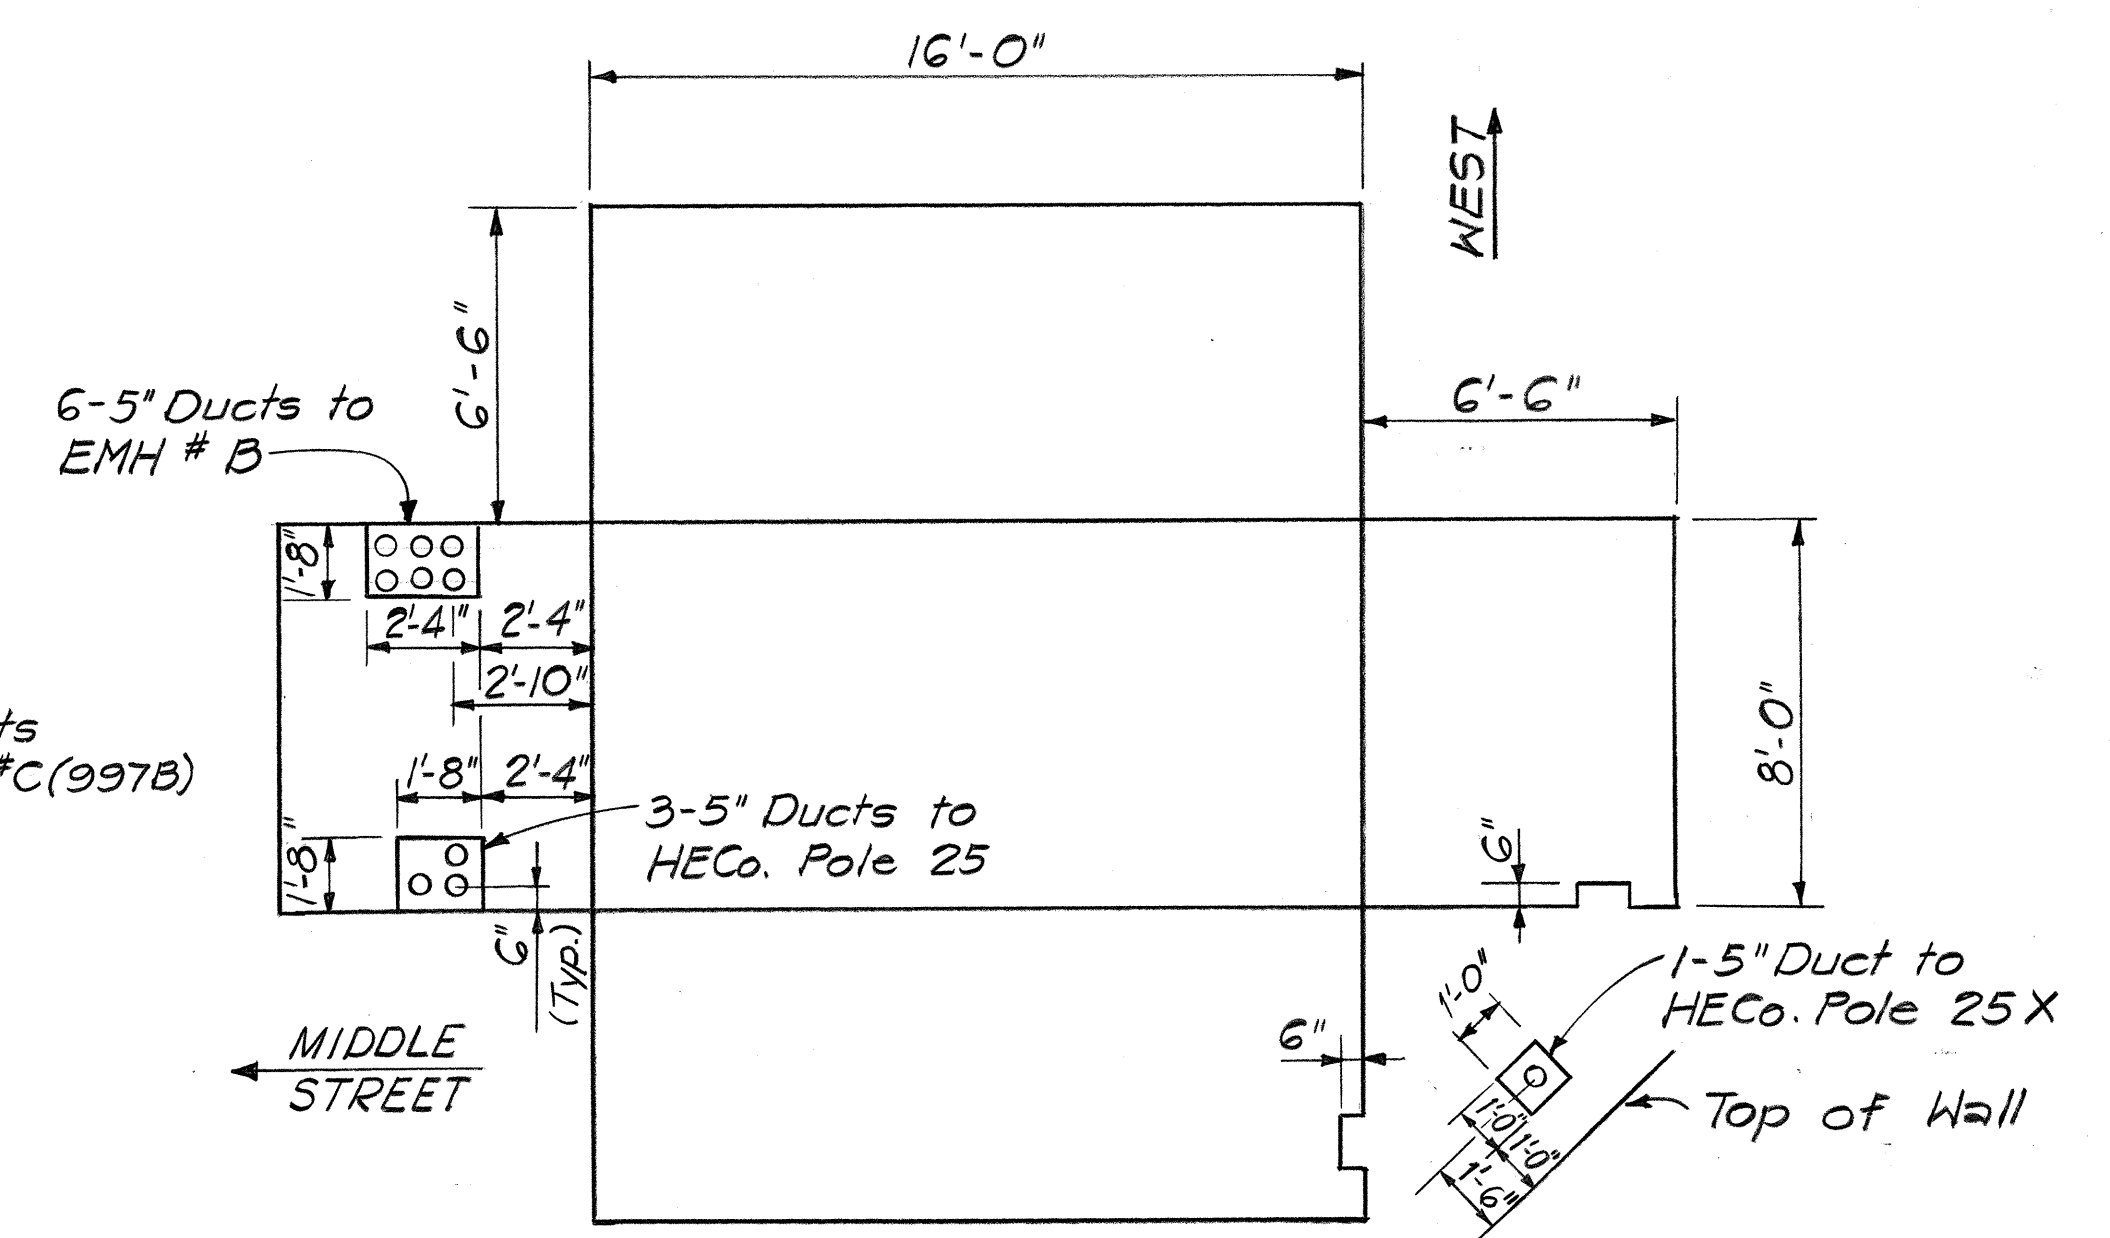

EMH #C, TYPE #6
(#997-B)

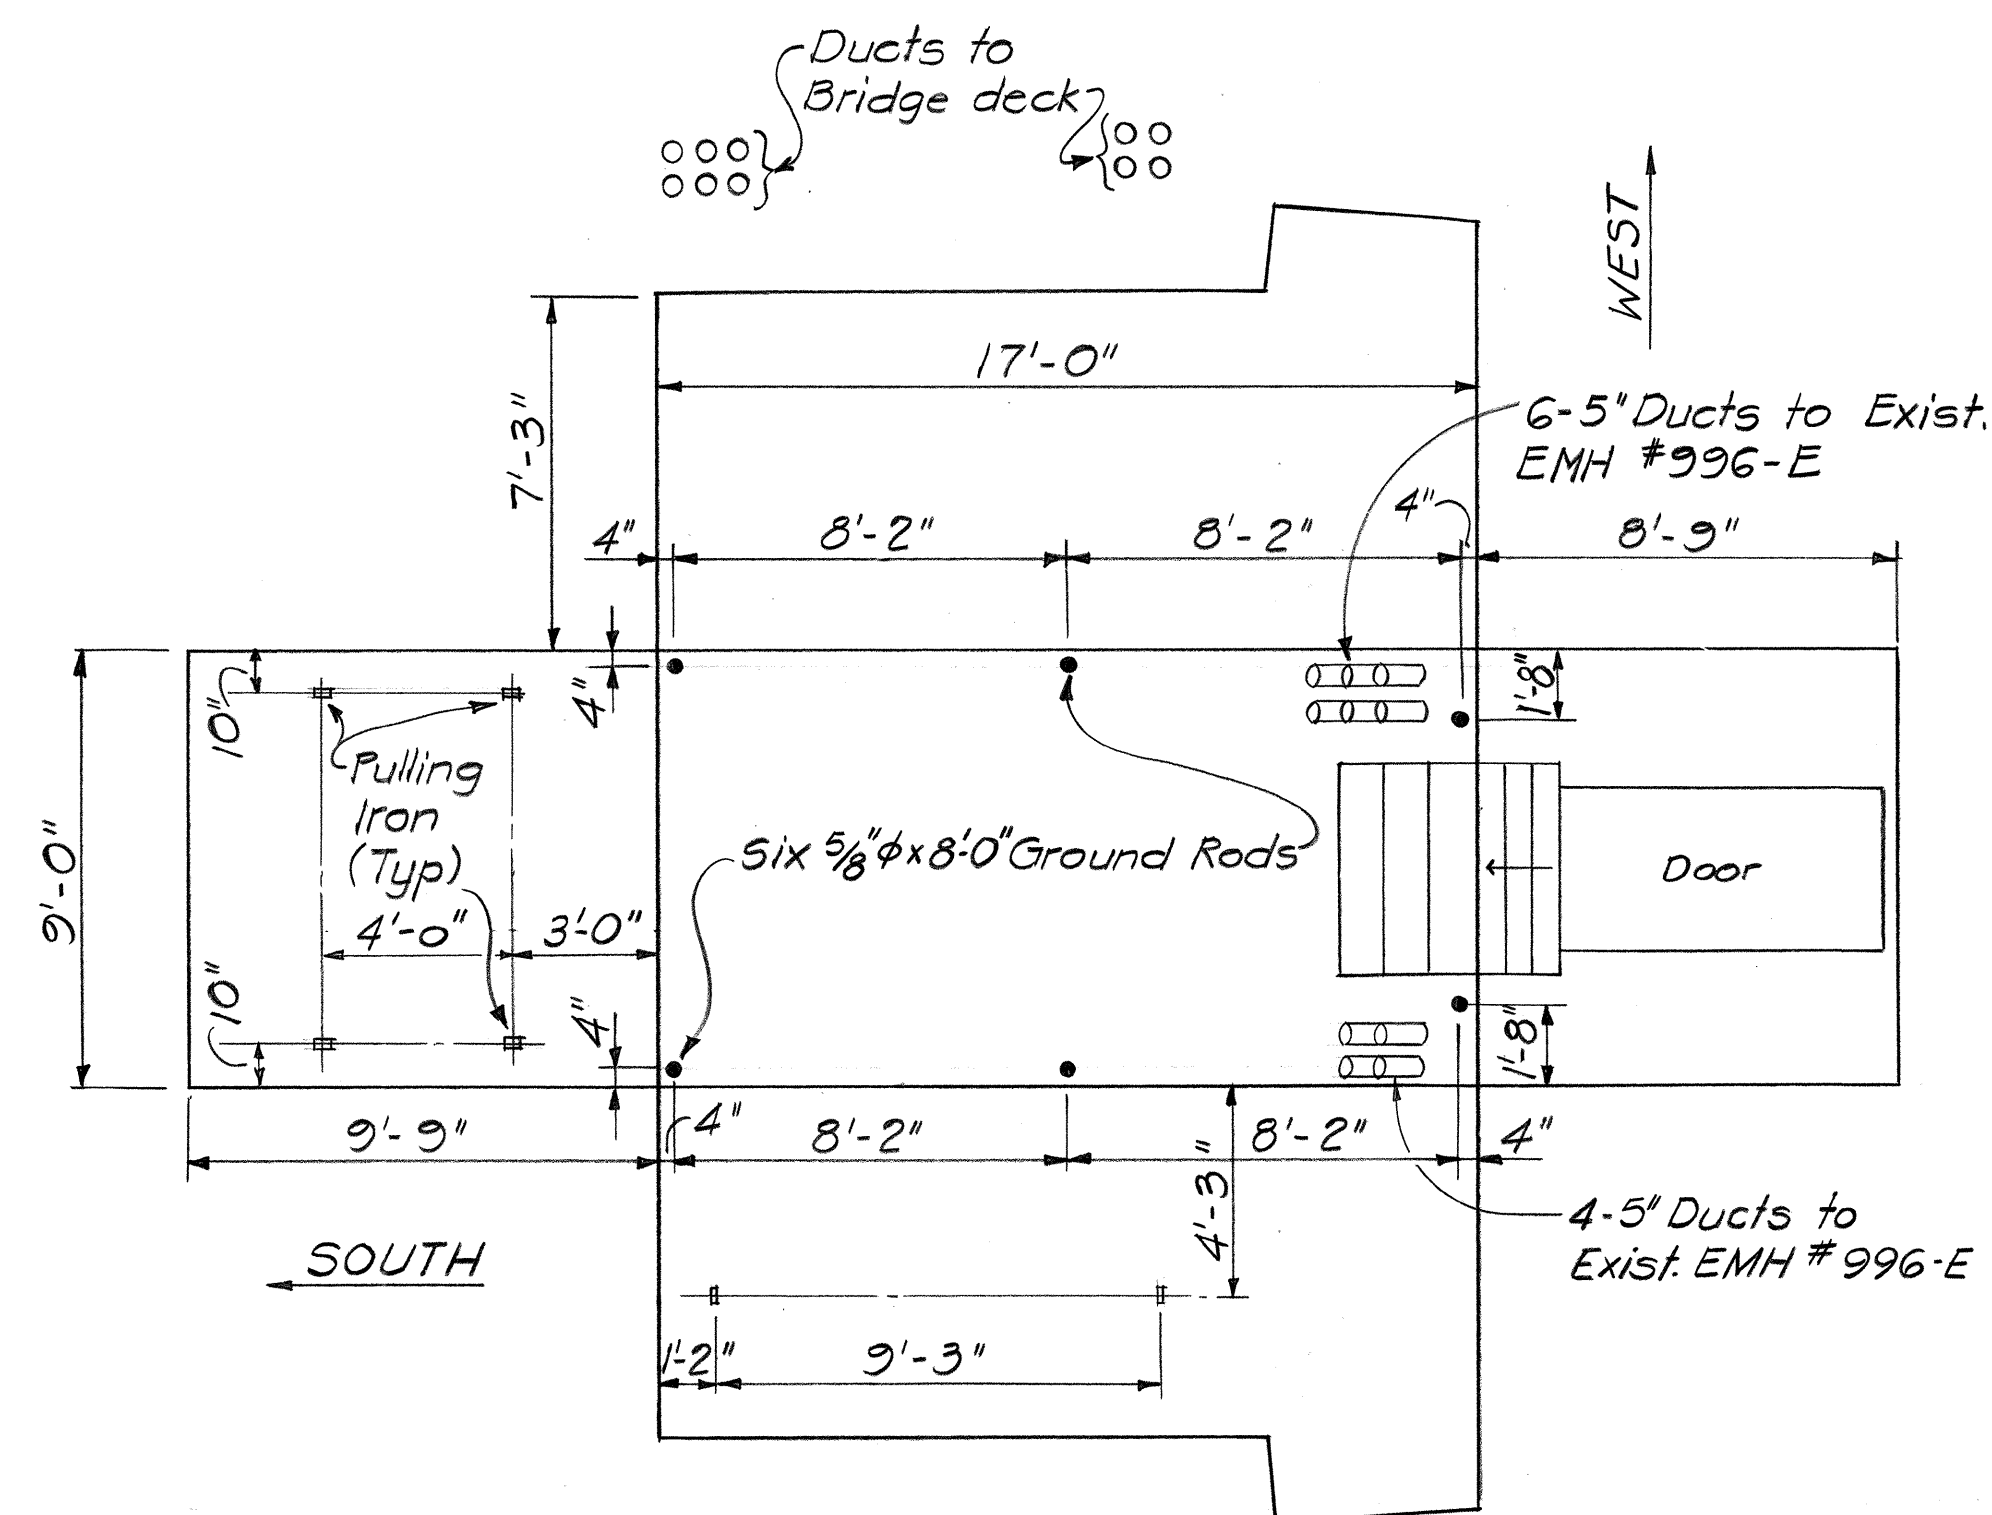


EHH #996-D
(HANDHOLE 'B')

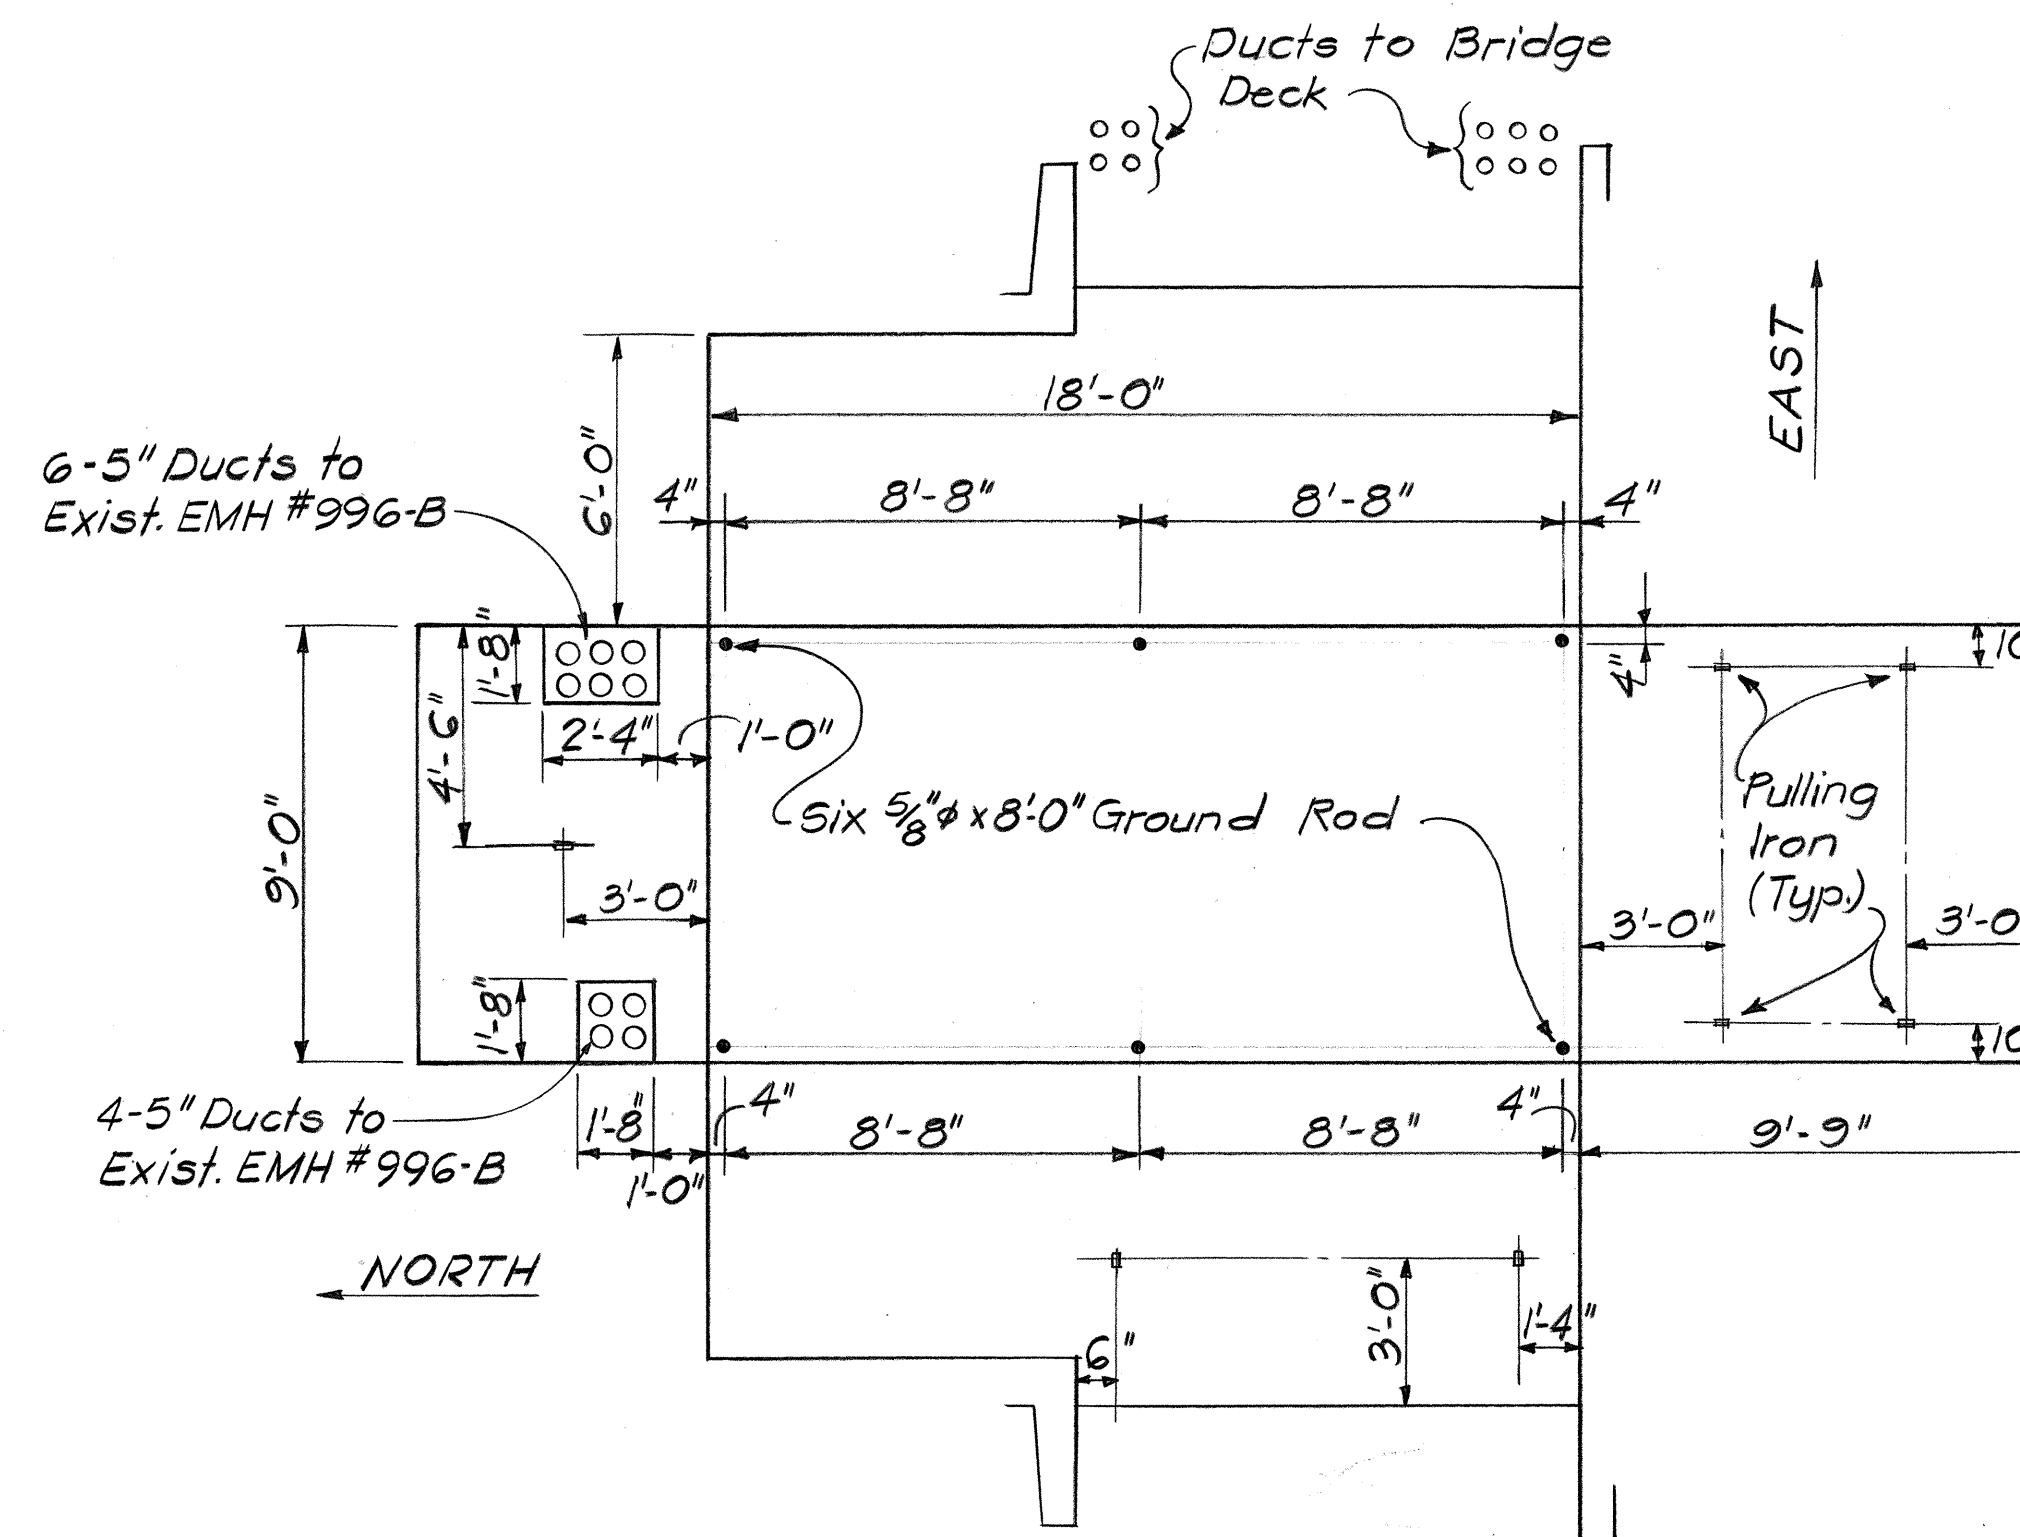

EHH #996-C
(HANDHOLE 'A')

APPROVED

By *J. Karamoto*
Hawaiian Electric Co., Inc. Date *8/10/77*

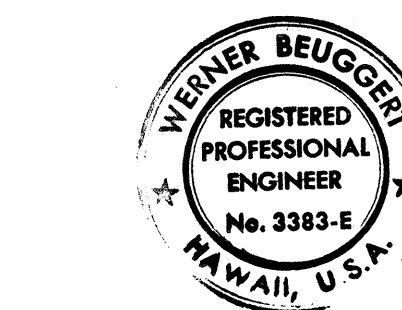

THIS WORK WAS PREPARED BY ME
OR UNDER MY SUPERVISION.

Werner Beugert

STATE OF HAWAII
DEPARTMENT OF TRANSPORTATION
HIGHWAYS DIVISION

**MANHOLE WALL ELEVATIONS
ELECTRIC**

INTERSTATE ROUTE H-1
PROJECT NO. I-HI-1 (131): 17






SCALE: 1/4" = 1'-0" DATE: AUG. 31, 1977

SHEET NO. U-5 OF U-23 SHEETS

FED. ROAD DIST. NO.	STATE	FED. AID PROJ. NO.	FISCAL YEAR	SHEET NO.	TOTAL SHEETS
HAWAII	HAW.	I-H-1(131):17	1977	178	394

GENERAL NOTES


- SPECIFICATION FOR CONSTRUCTION OF UNDERGROUND FACILITIES, CS7001, SHALL GOVERN.
- EXCAVATIONS: EXCAVATE FOR HANDHOLE TO ACCURATE ALIGNMENT, GRADES AND DIMENSIONS AS SHOWN ON DRAWINGS. ALL EXCAVATION MUST BE APPROVED BY THE ENGINEERING DEPT., HECO, BEFORE ANY CONCRETE IS POURED. ALL OVEREXCAVATION SHALL BE FILLED WITH CONCRETE USED FOR THE HANDHOLE OR BACKFILLED WITH COMPACTED SELECTED MATERIAL AS DIRECTED BY THE ENGINEER (HECO).
- BACKFILL: REMOVE ALL DEBRIS BEFORE BACKFILLING. BACKFILL IN ACCORDANCE WITH LATEST SPECIFICATIONS OF DIVISION OF HIGHWAYS, STATE OF HAWAII.
- ALL WORK TO BE DONE IN DRY.
- CONCRETE COMPRESSIVE STRENGTH - 3000 PSI IN 28 DAYS.
- MIXING: READY MIXED A.S.T.M., C-94.
- REINFORCING: ROUND DEFORMED BARS, (CLEAN & NEW).
- SPLICE IN ACCORDANCE WITH LATEST AASHTO STANDARDS.
- CURING: KEEP CONCRETE MOIST AT LEAST 7 DAYS AFTER POURING (BY APPROVED METHOD).
- FINISH: ALL SURFACES SMOOTH AND FREE FROM DEFECTS. TOP OF HANDHOLE - WOOD FLOATED HANDHOLE FLOOR - STEEL TROWELED INSIDE WALLS & CEILING - CEMENT WASHED
- INSTALL ALL INSERTS, INCLUDING PULLING IRONS, GROUND RODS, ETC., BEFORE POURING CONCRETE.
- POURING: NOTIFY THE HECO CONTRACTING & INSPECTION DIVISION, PH. 548-4427 OR 548-4428, 24 HOURS BEFORE POURING ANY CONCRETE. ALL CONCRETE POURING SHALL BE DONE IN THE PRESENCE OF AN HECO ENGINEER OR INSPECTOR.
- FORMS: MAKE OF GOOD SOUND LUMBER OF SUFFICIENT STRENGTH, WATER TIGHT AND CONFORMING TO SHAPE AND DIMENSIONS INDICATED ON DRAWINGS.
- SLOPE HANDHOLE FLOOR DRAIN 1" TOWARDS SUMP.
- ALL WORK SHALL BE SUBJECT TO INSPECTION BY THE HAWAIIAN ELECTRIC CO., INC. AND DIVISION OF HIGHWAYS, STATE OF HAWAII.
- ALL MATERIALS SHALL BE NEW AND MANUFACTURED IN THE UNITED STATES OF AMERICA.
- SEE HANDHOLE WALL ELEVATION DRAWINGS FOR NUMBER, SIZE AND LOCATION OF DUCT ENTRANCES AND PULLING IRONS (HECO-DWG. NO. 24870) SHEET U-5.
- FOR MISCELLANEOUS HANDHOLE DETAILS, REFER TO HECO DWG. 16688A (SHEETS 1 & 2).

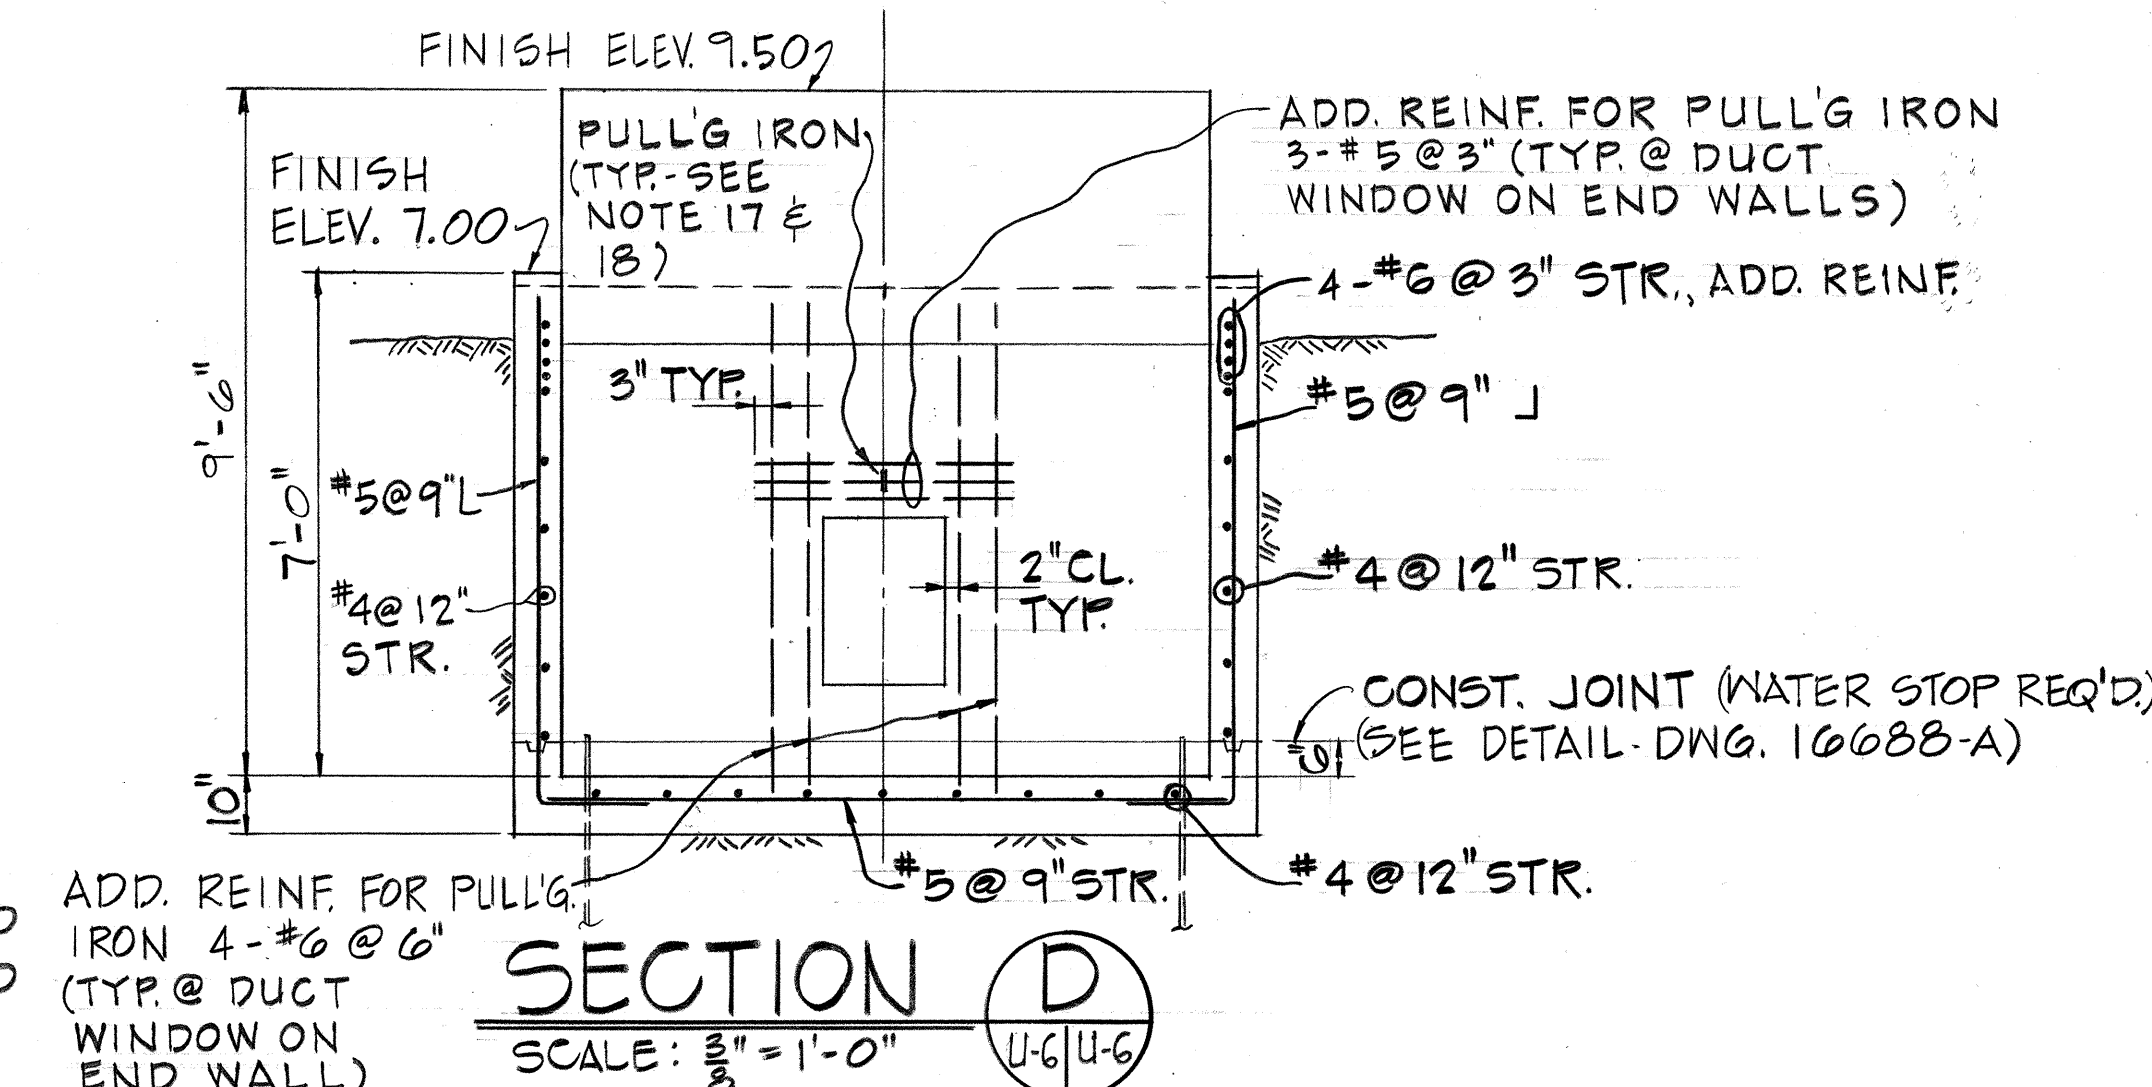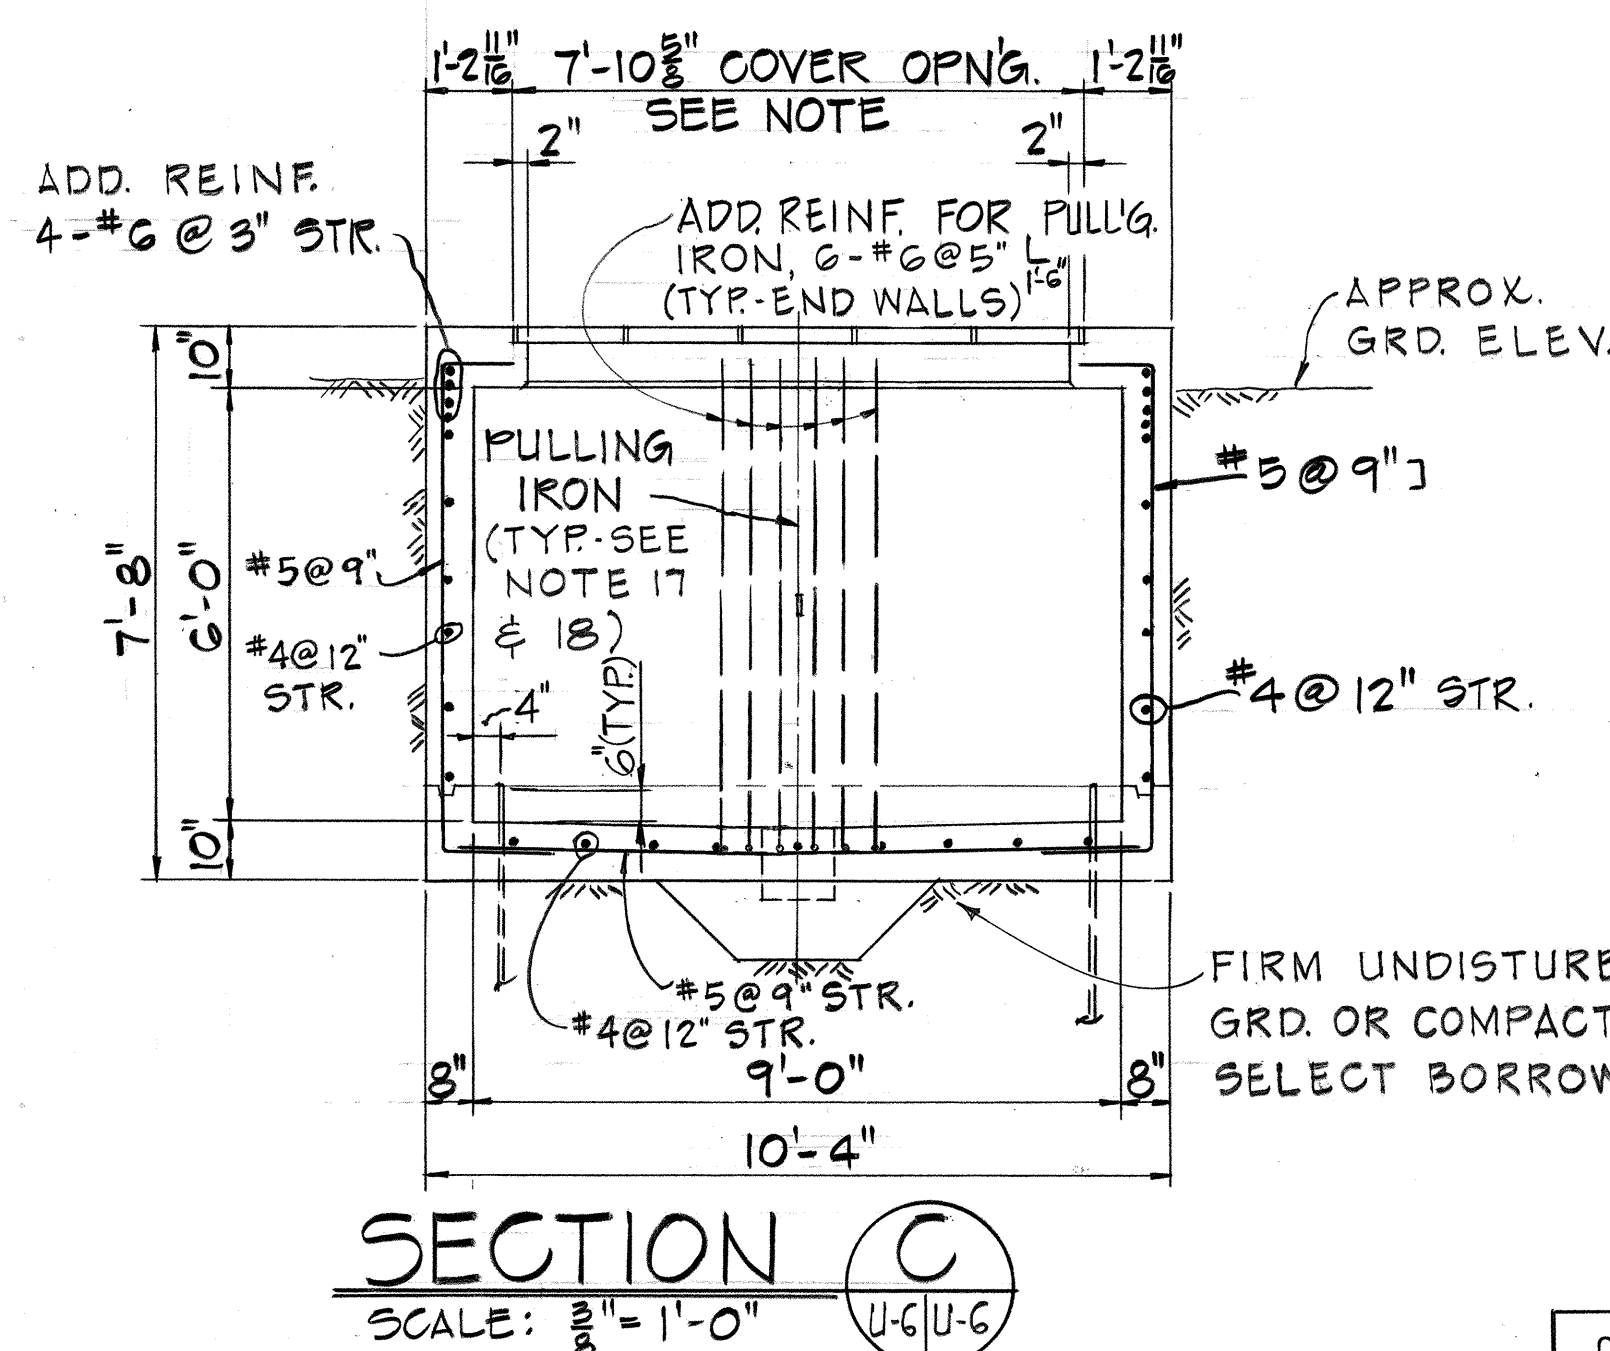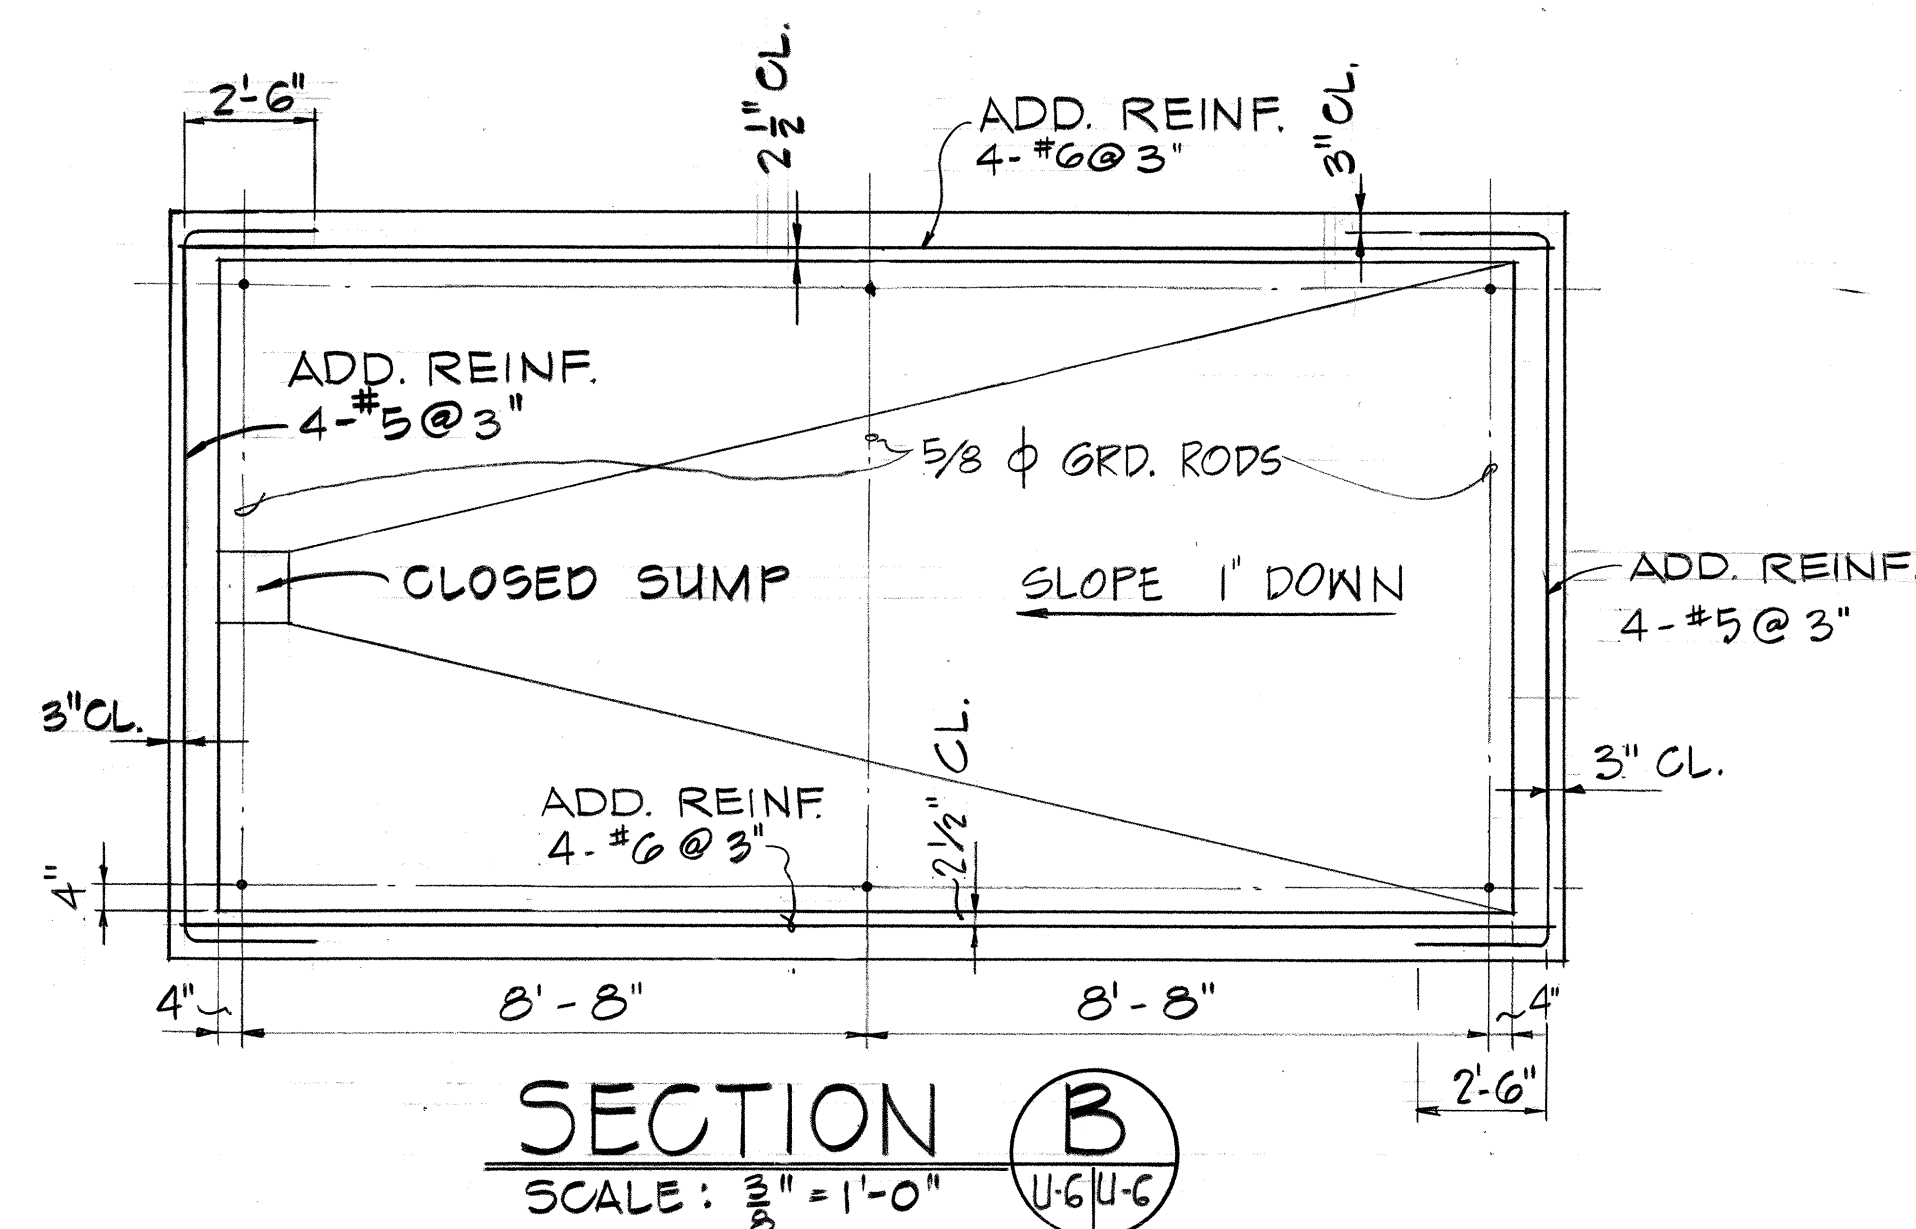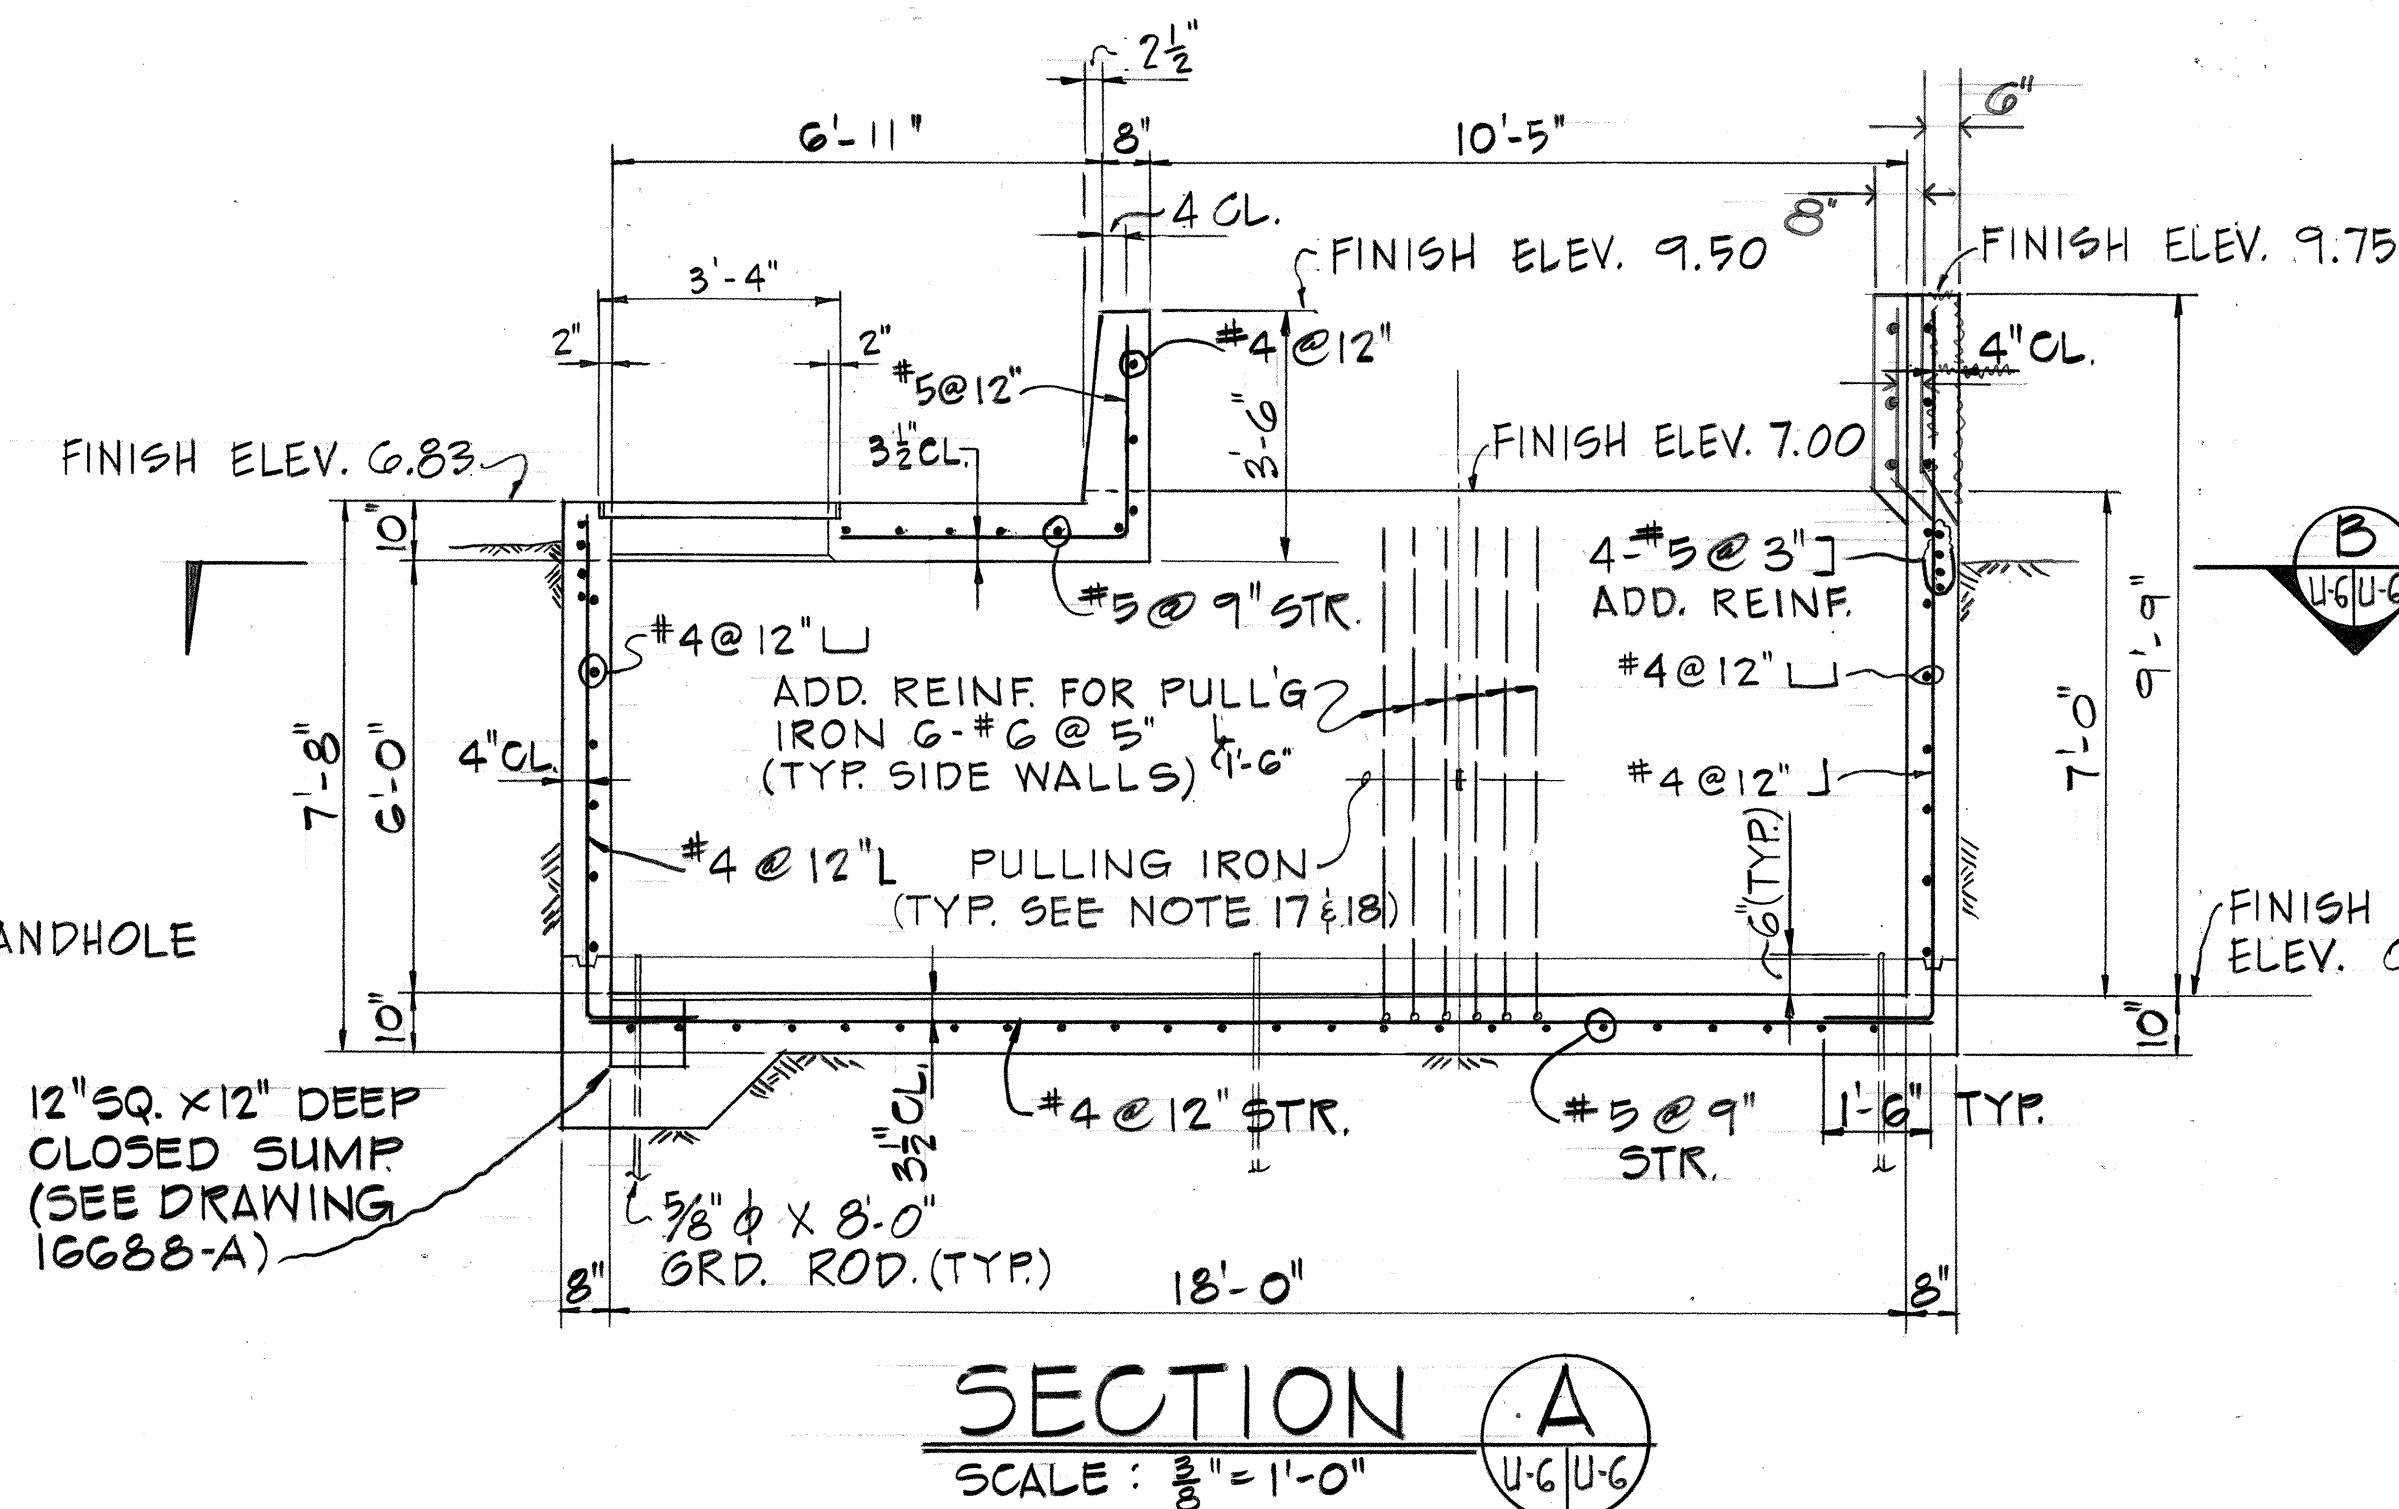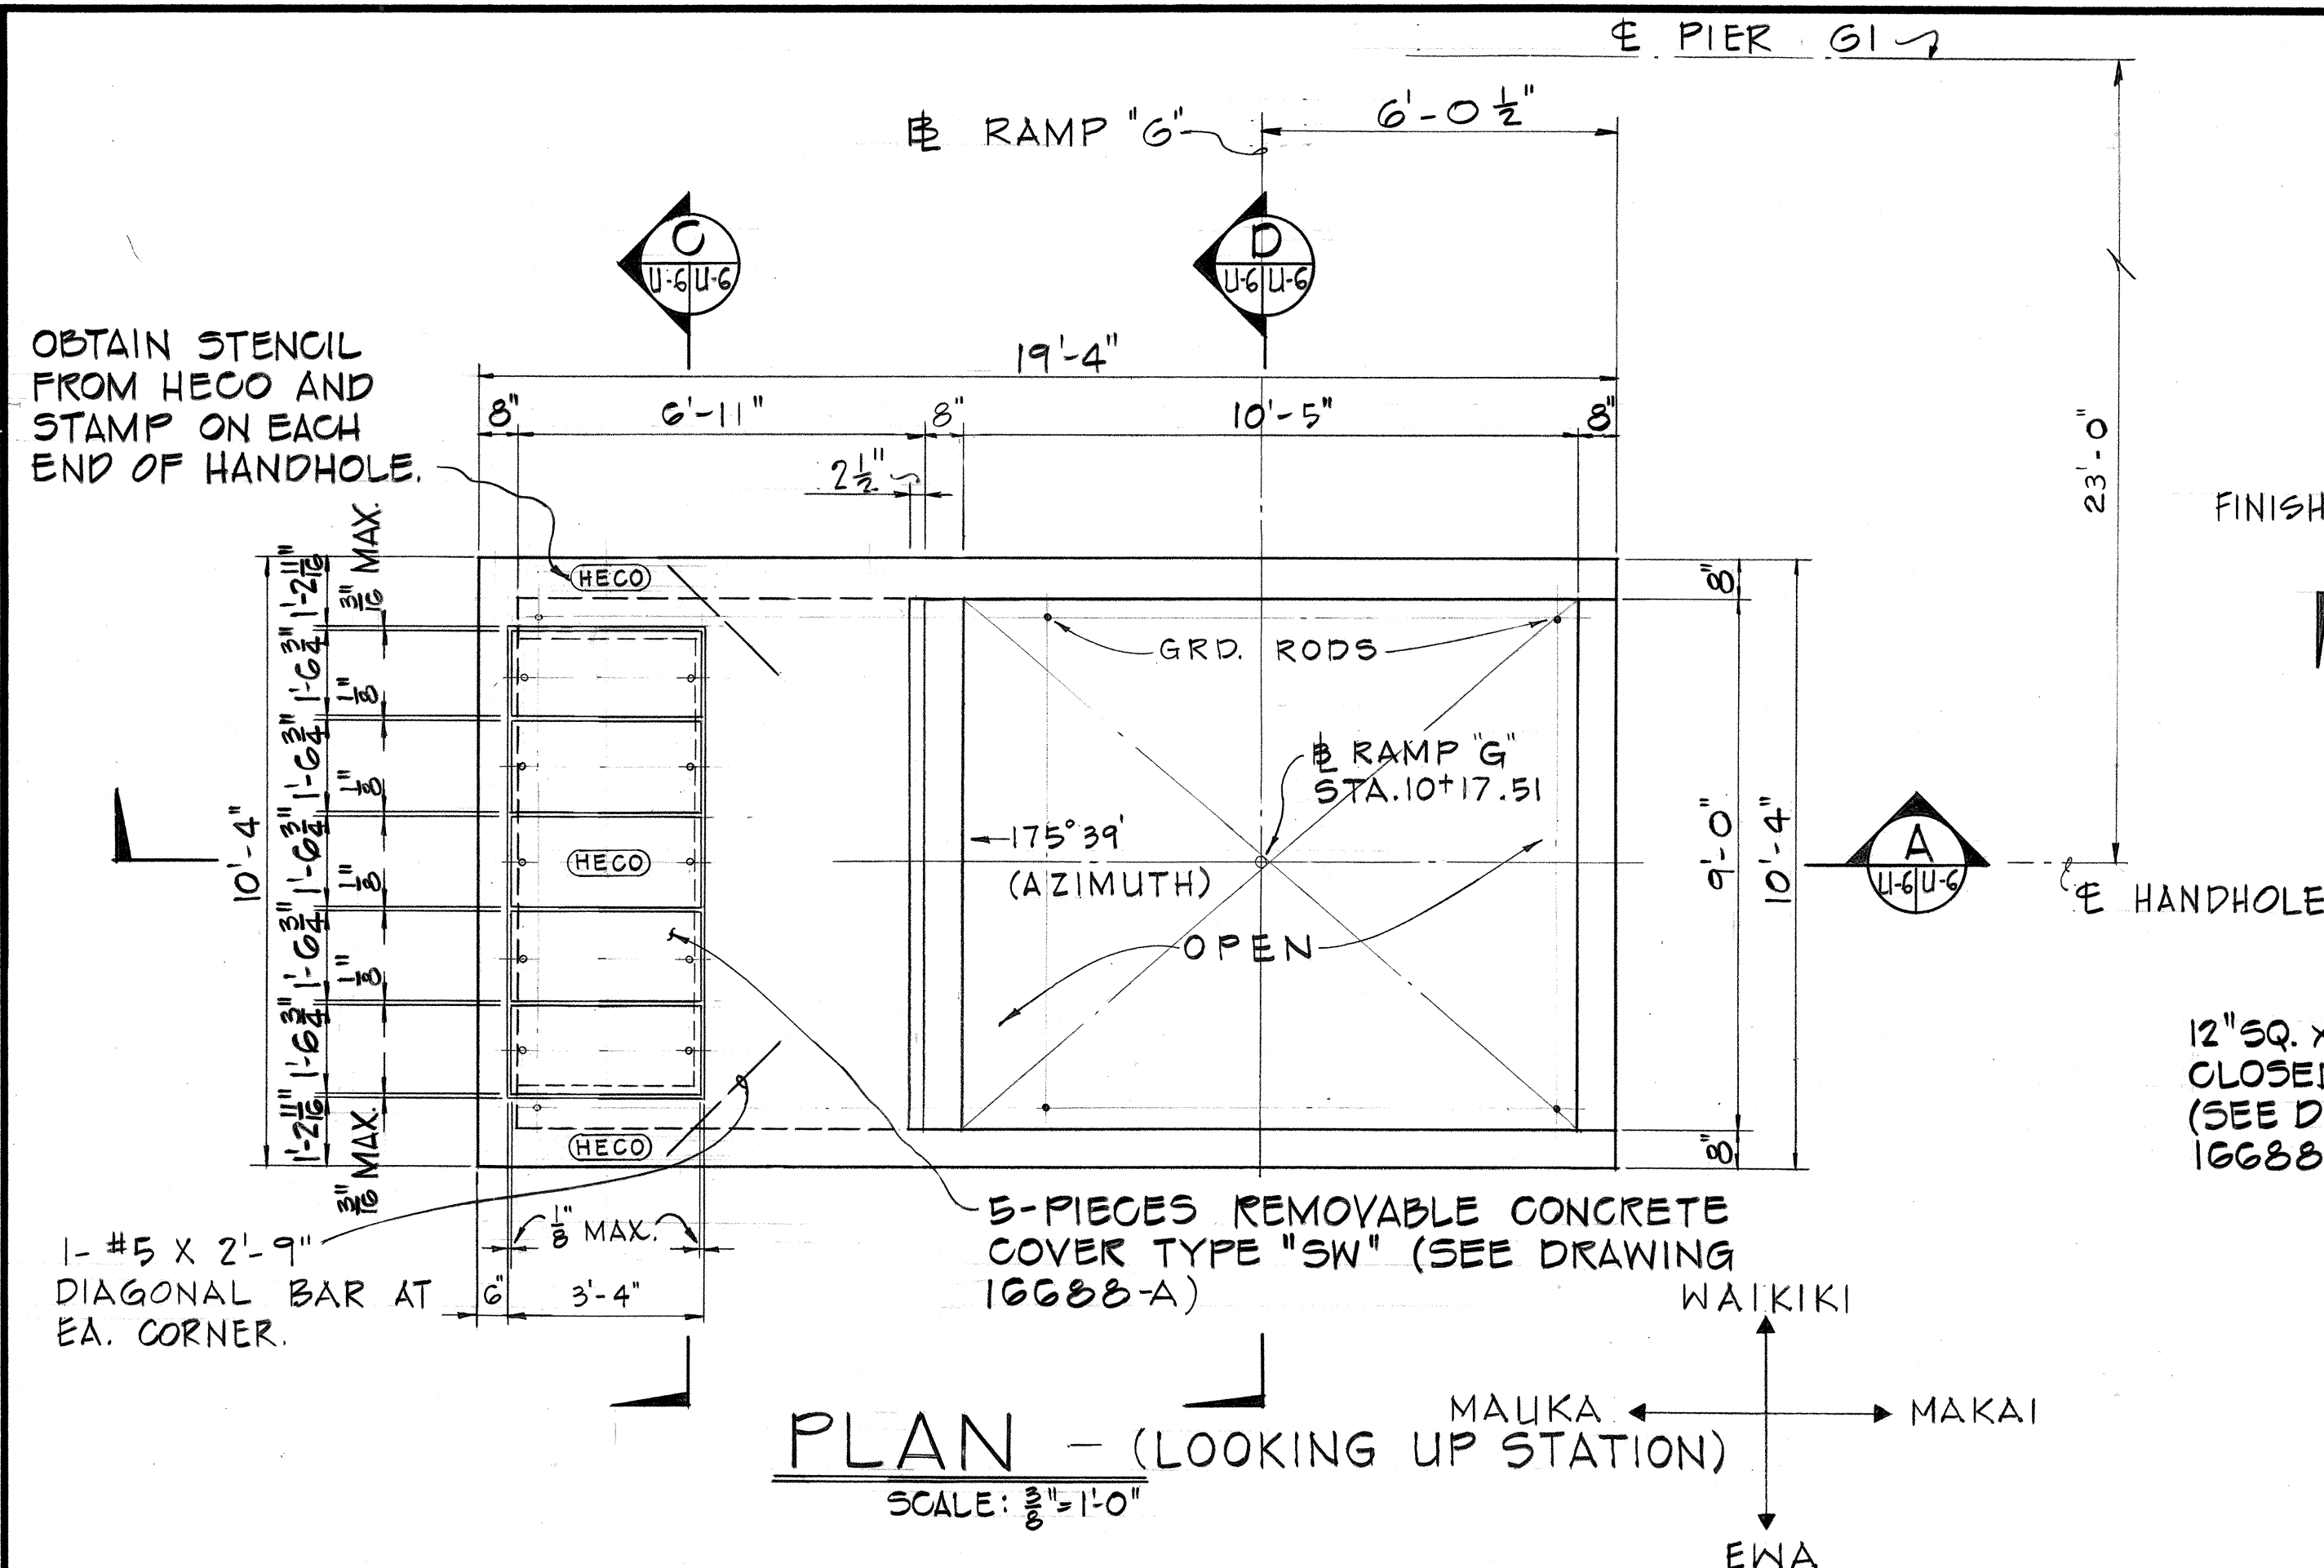

QUANTITY OF MATERIALS	
CONCRETE	19.5 CU. YD.
REINFORCING	1663.5 LBS.
REINFORCING - ADDITIONAL (PULLING IRON ONLY-EA.)	90 LBS.
MISCELLANEOUS STEEL (PULLING IRON ONLY)	10.9 LBS.

APPROVED
 30 ST. H. K. Stewart
 CIVIL-STRUCTURAL
 06/11/77
 ELECTRICAL
 HAWAIIAN ELECTRIC COMPANY, INC.

HECO, INC. DRAWING NUMBER	
2 3 3 4 9	
STATE OF HAWAII	
DEPARTMENT OF TRANSPORTATION	
HIGHWAYS DIVISION	
ELECTRIC HANDHOLE 'A'	
INTERSTATE ROUTE H-1	
PROJECT NO. I-H-1(131):17	
SCALE: AS NOTED	DATE: AUG. 31, 77
SHEET NO. U-6 OF U-23 SHEETS	

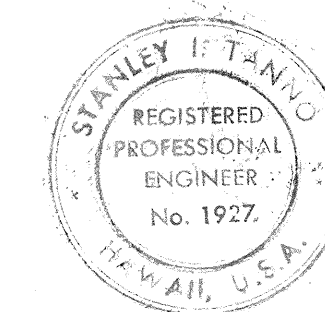


THIS WORK WAS PREPARED BY
 AS OR UNDER MY SUPERVISION
 Stanley I. Tanno 6/2/77


FED. ROAD DIST. NO.	STATE	FED. AID PROJ. NO.	FISCAL YEAR	SHEET NO.	TOTAL SHEETS
HAWAII	HAW.	I-H1-1(131)17	1977	179	394

GENERAL NOTES


- SPECIFICATION FOR CONSTRUCTION OF UNDERGROUND FACILITIES CS7001, SHALL GOVERN.
- EXCAVATIONS: EXCAVATE FOR HANDHOLE TO ACCURATE ALIGNMENT, GRADES AND DIMENSIONS AS SHOWN ON DRAWINGS. ALL EXCAVATION MUST BE APPROVED BY THE ENGINEERING DEPT., HECO, BEFORE ANY CONCRETE IS POURED. ALL OVEREXCAVATION SHALL BE FILLED WITH CONCRETE USED FOR THE HANDHOLE OR BACKFILLED WITH COMPACTED SELECTED MATERIAL AS DIRECTED BY THE ENGINEER (HECO).
- BACKFILL: REMOVE ALL DEBRIS BEFORE BACKFILLING. BACKFILL IN ACCORDANCE WITH THE LATEST SPECIFICATIONS OF DIVISION OF HIGHWAYS, STATE OF HAWAII.
- ALL WORK TO BE DONE IN DRY.
- CONCRETE COMPRESSIVE STRENGTH - 3000 PSI IN 28 DAYS.
- MIXING: READY MIXED A.S.T.M., C-94.
- REINFORCING: ROUND DEFORMED BARS, (CLEAN & NEW).
- SPLICE IN ACCORDANCE WITH LATEST AASHTO STANDARDS.
- CURING: KEEP CONCRETE MOIST AT LEAST 7 DAYS AFTER POURING (BY APPROVED METHOD).
- FINISH: ALL SURFACES SMOOTH AND FREE FROM DEFECTS.
HANDHOLE FLOOR - STEEL TROWELLED
WALLS & CEILING - CEMENT WASHED
- INSTALL ALL INSERTS, INCLUDING PULLING IRONS, GROUND RODS, ETC., BEFORE POURING CONCRETE.
- POURING: NOTIFY THE HECO CONTRACTING & INSPECTION DIVISION, PH. 548-4427 OR 548-4428, 24 HOURS BEFORE POURING ANY CONCRETE. ALL CONCRETE POURING SHALL BE DONE IN THE PRESENCE OF AN HECO ENGINEER OR INSPECTOR.
- FORMS: MAKE OF GOOD SOUND LUMBER OF SUFFICIENT STRENGTH, WATER TIGHT AND CONFORMING TO SHAPE AND DIMENSIONS INDICATED ON DRAWINGS.
- SLOPE HANDHOLE FLOOR DRAIN 1" TOWARDS SUMP.
- ALL WORK SHALL BE SUBJECT TO INSPECTION BY THE HAWAIIAN ELECTRIC CO., INC. AND DIVISION OF HIGHWAYS, STATE OF HAWAII.
- ALL MATERIALS SHALL BE NEW AND MANUFACTURED IN THE UNITED STATES OF AMERICA.
- SEE HANDHOLE WALL ELEVATION DRAWINGS FOR NUMBER, SIZE AND LOCATION OF DUCT ENTRANCES AND PULLING IRONS (HECO-DWG. NO. 24871) SHEET U-5.
- FOR MISCELLANEOUS HANDHOLE DETAILS, REFER TO HECO DWG. 16688-A (SHEETS 1 & 2).
- HOLLOW METAL DOOR W/THRESHOLD (3'-0"x6'-8"x1-3/4")-DOOR SHALL BE MORTISED, DRILLED, TAPPED, AND REINFORCED FOR HARDWARE TO TEMPLATES. FINISH SHALL BE THE MANUFACTURER'S STANDARD BAKED-ON PRIMER. DOOR FRAMES SHALL BE OF NO. 16 GAUGE STEEL. THE LOCKSET (5211-NC-US10: GOV. NO. 86B-4), FURNISHED BY CONTRACTOR, SHALL BE KEYS TO HECO'S SYSTEM (HECO TO PROVIDE CYLINDER). FINISH PAINT DOOR WITH W.P. FULLER 260-XX "HOUSE & TRIM PAINT" COLORED "WYNWOOD".
- EXTERIOR SURFACES OF WALLS & ROOF SHALL BE WATER-SEAL PAINTED.

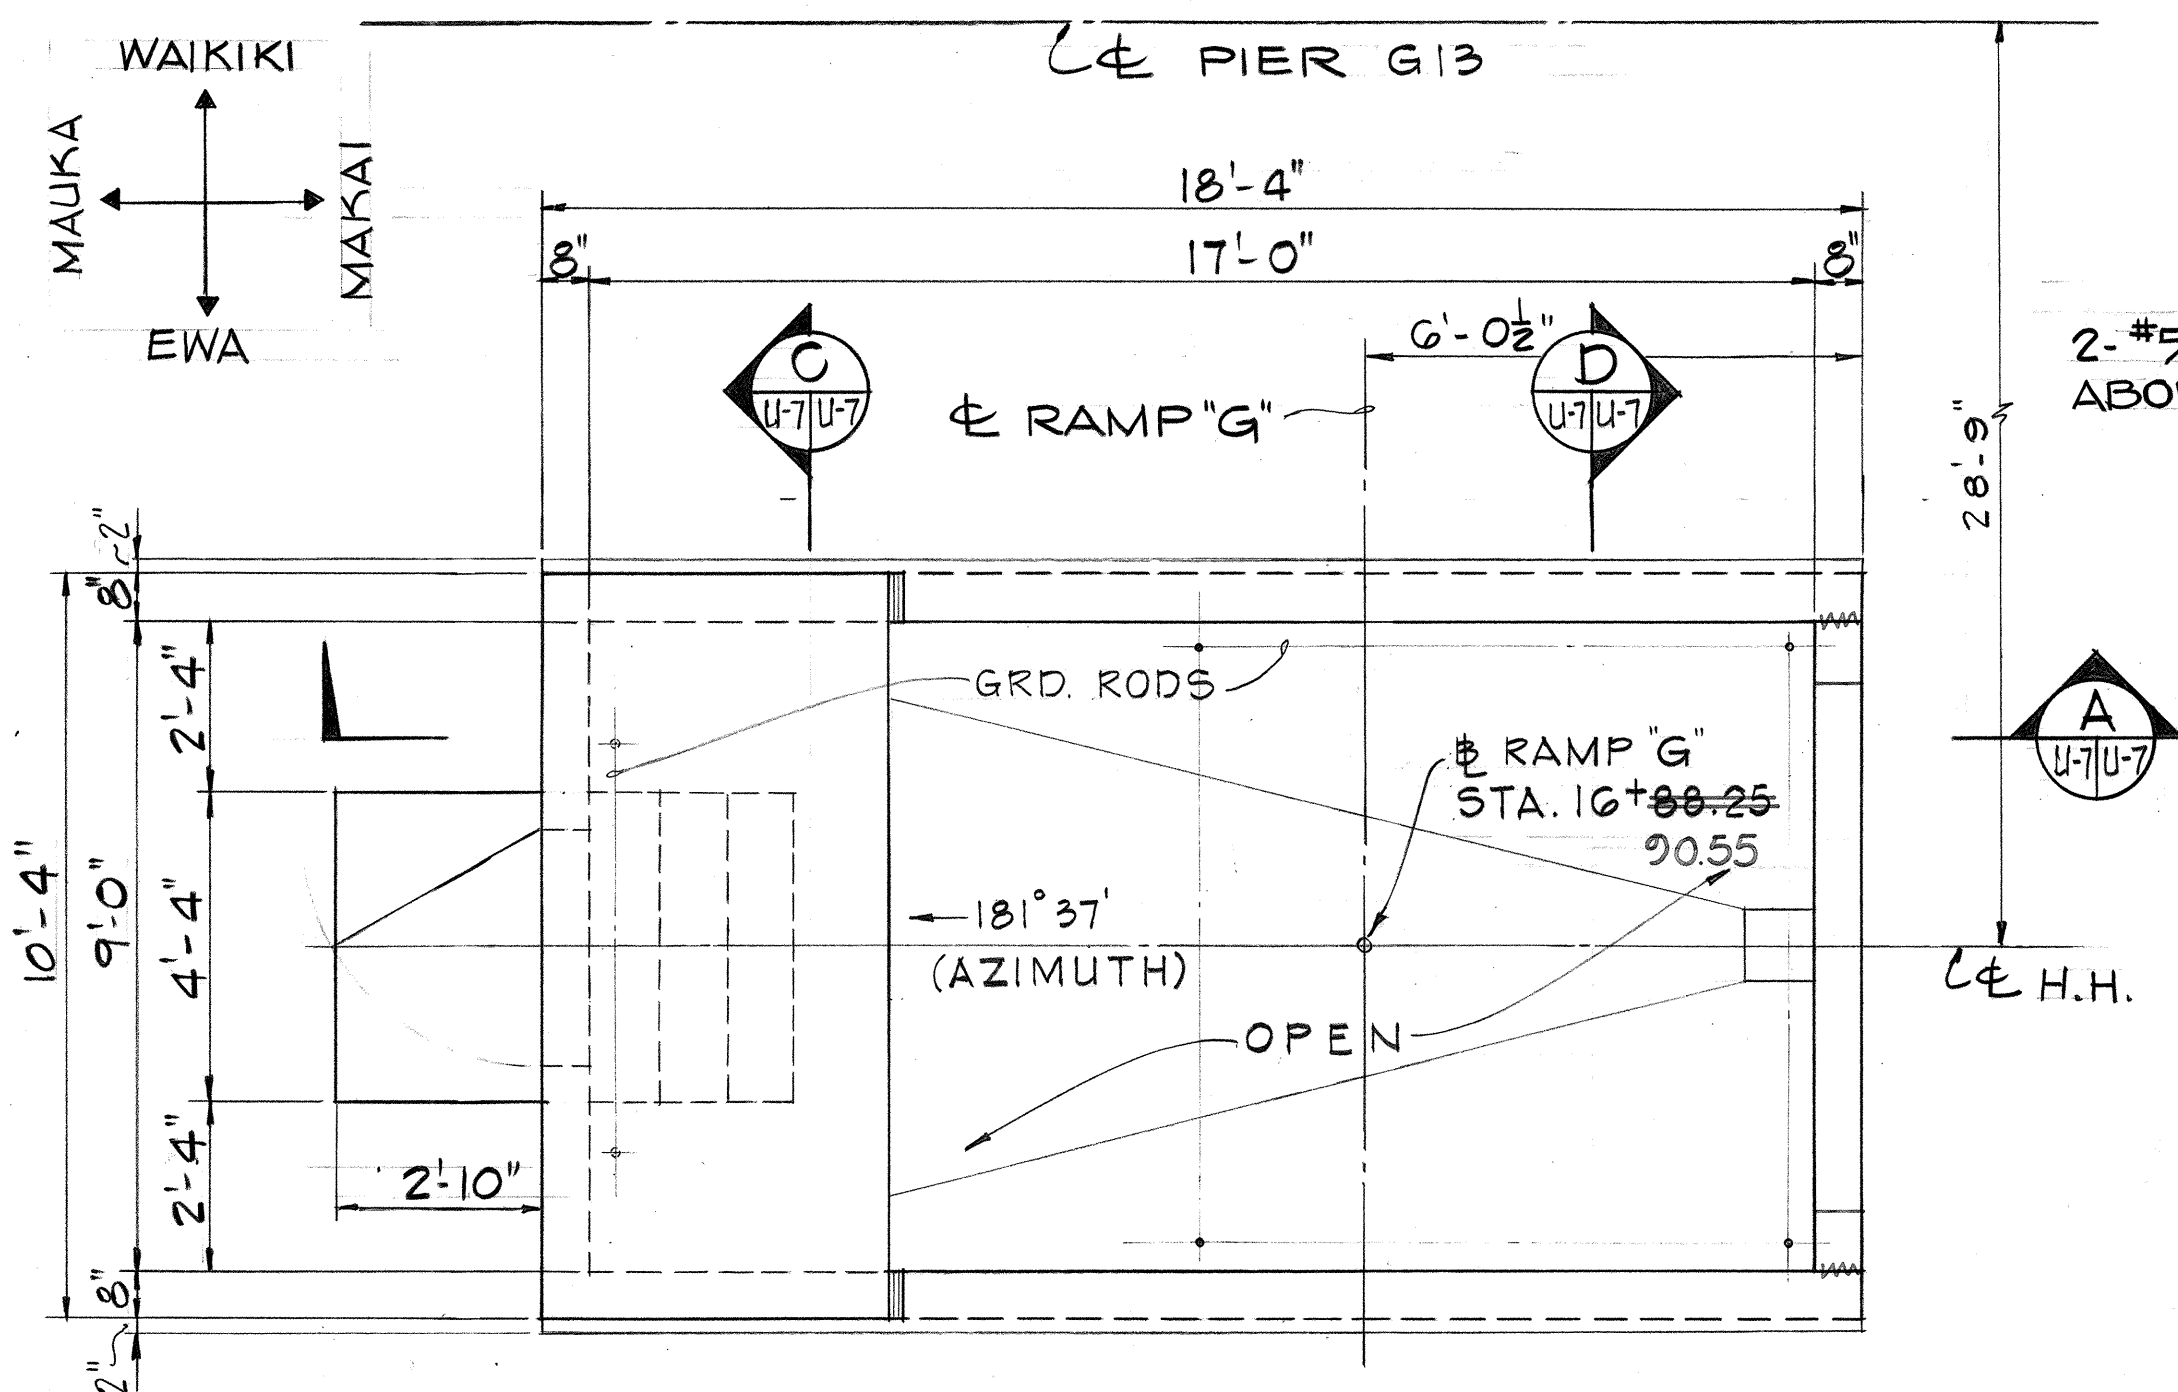


PLAN - (LOOKING UP STATION)
SCALE: 3/8"=1'-0"

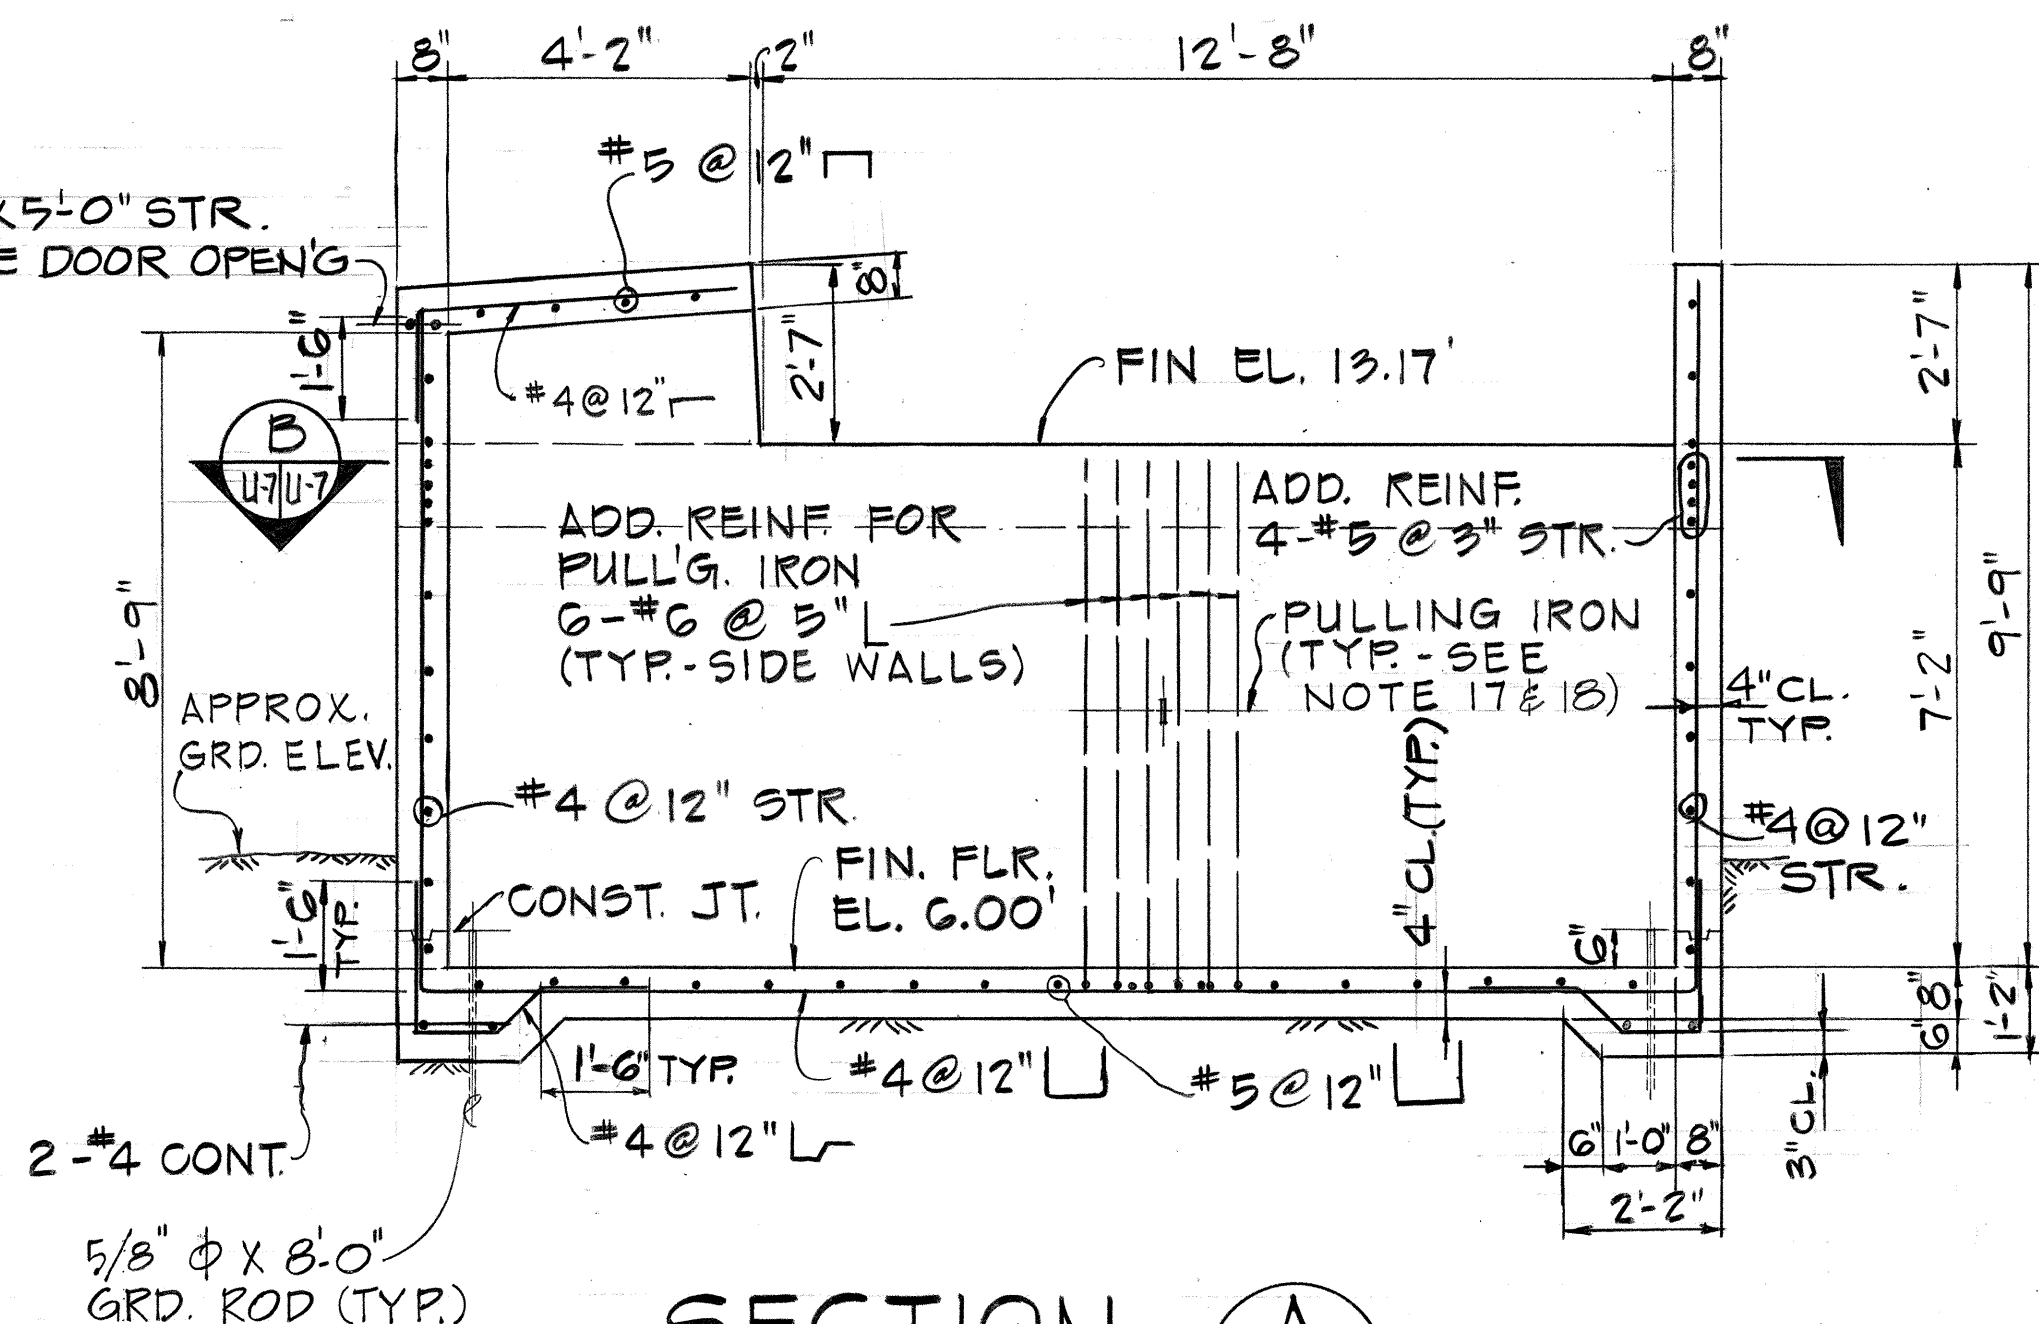


SECTION A
SCALE: 3/8"=1'-0"

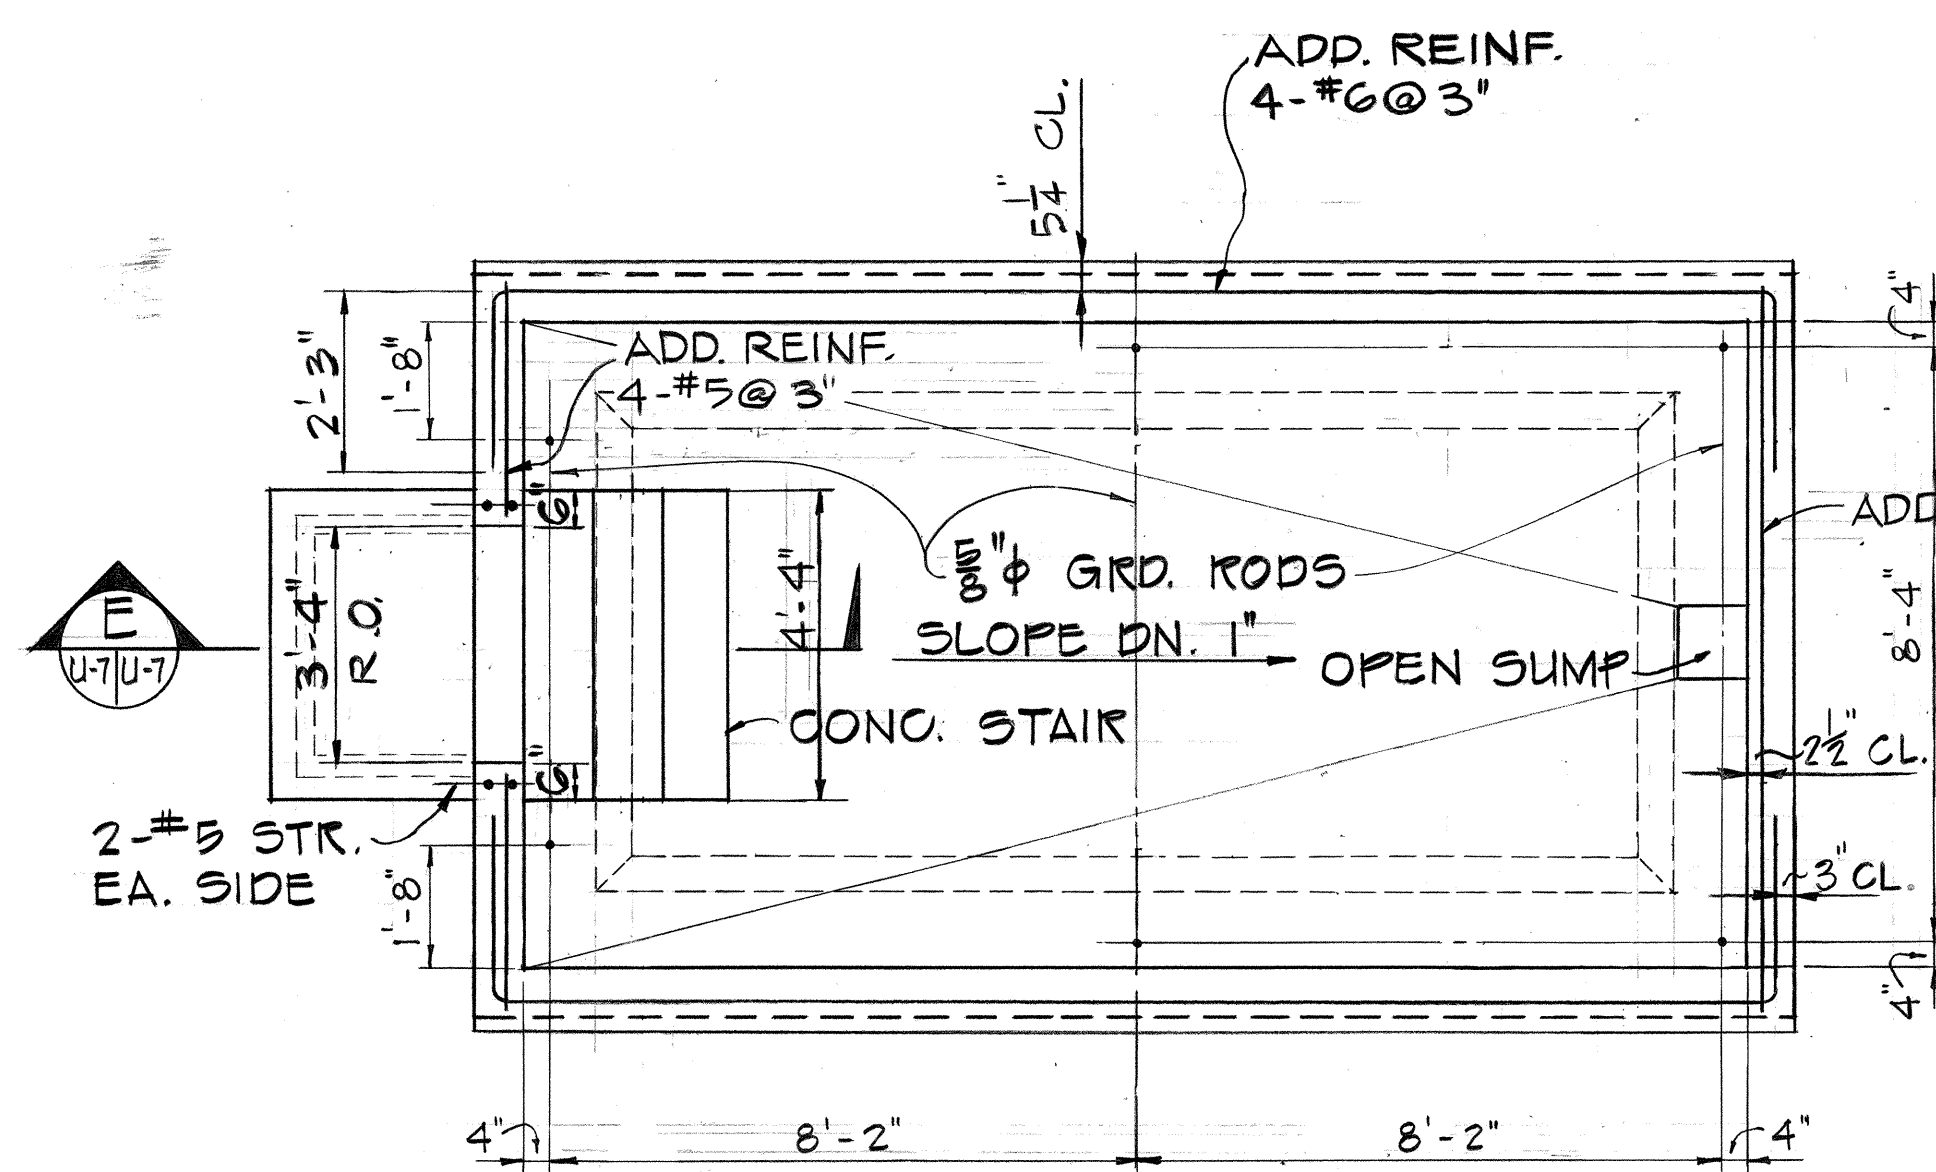


SECTION B
SCALE: 3/8"=1'-0"

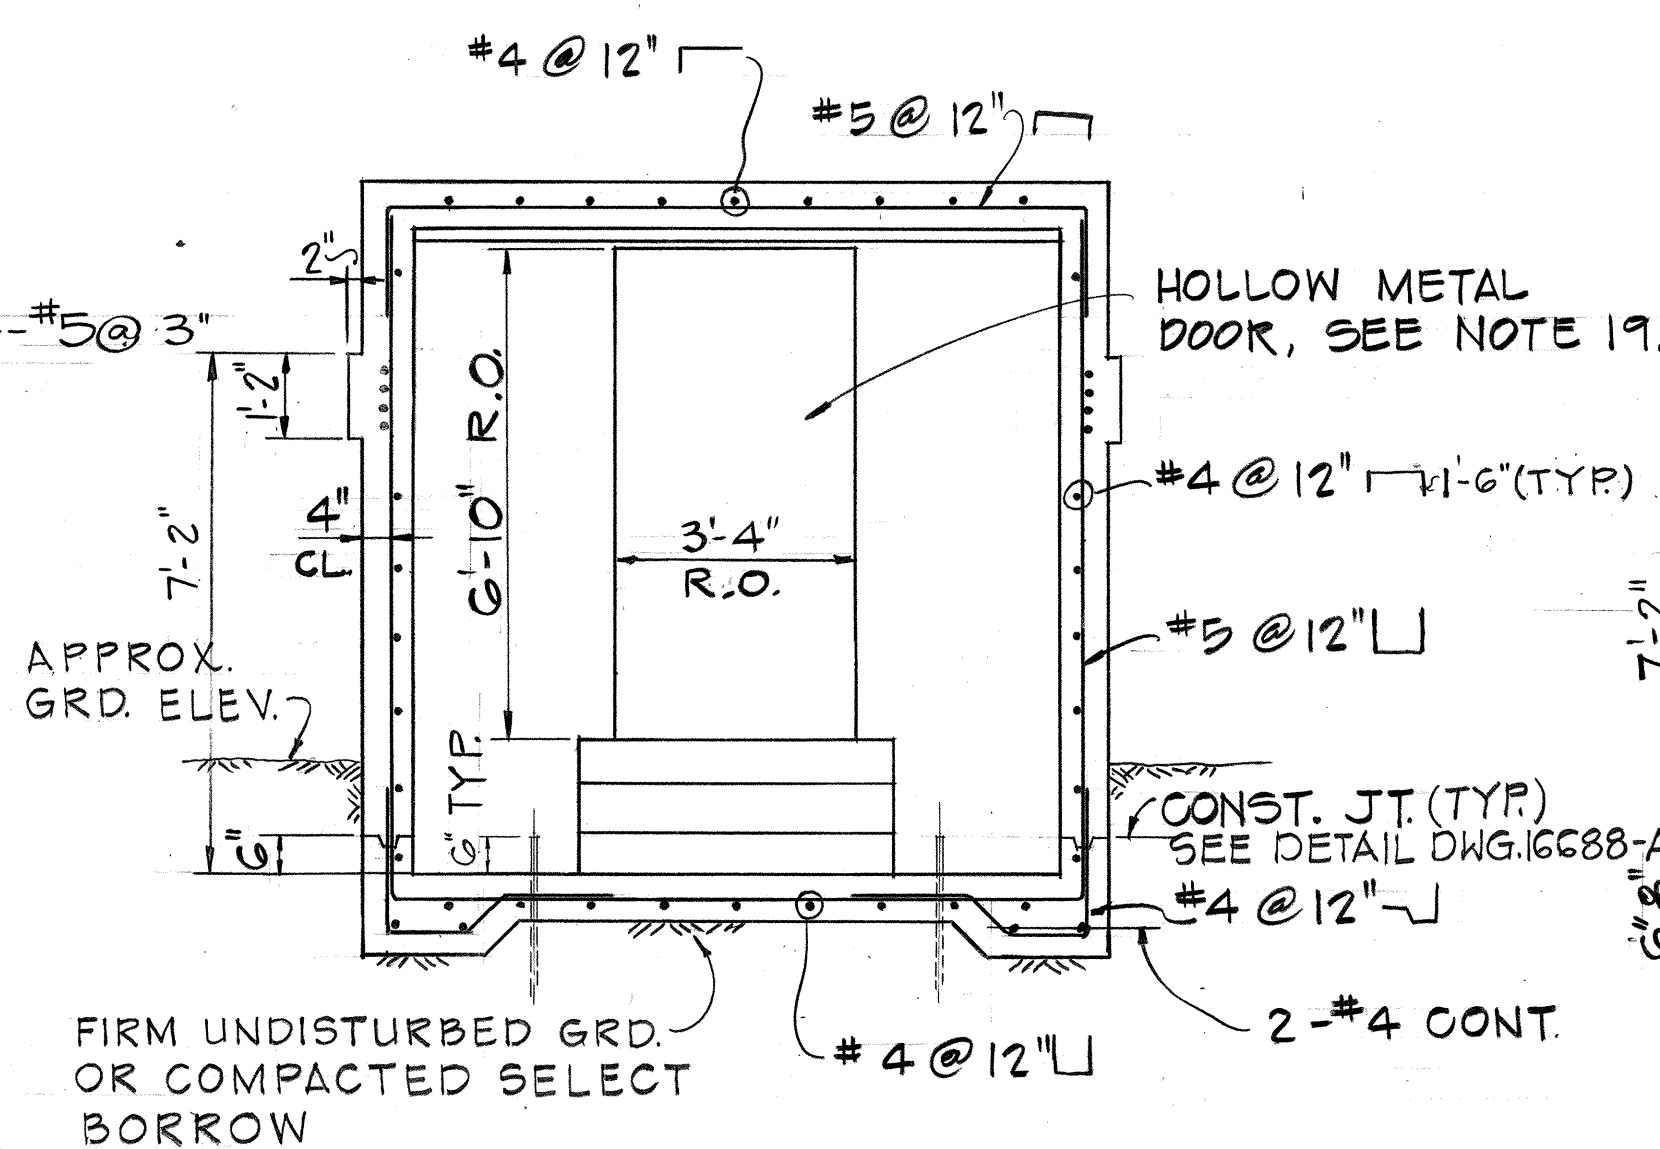

SECTION C
SCALE: 3/8"=1'-0"

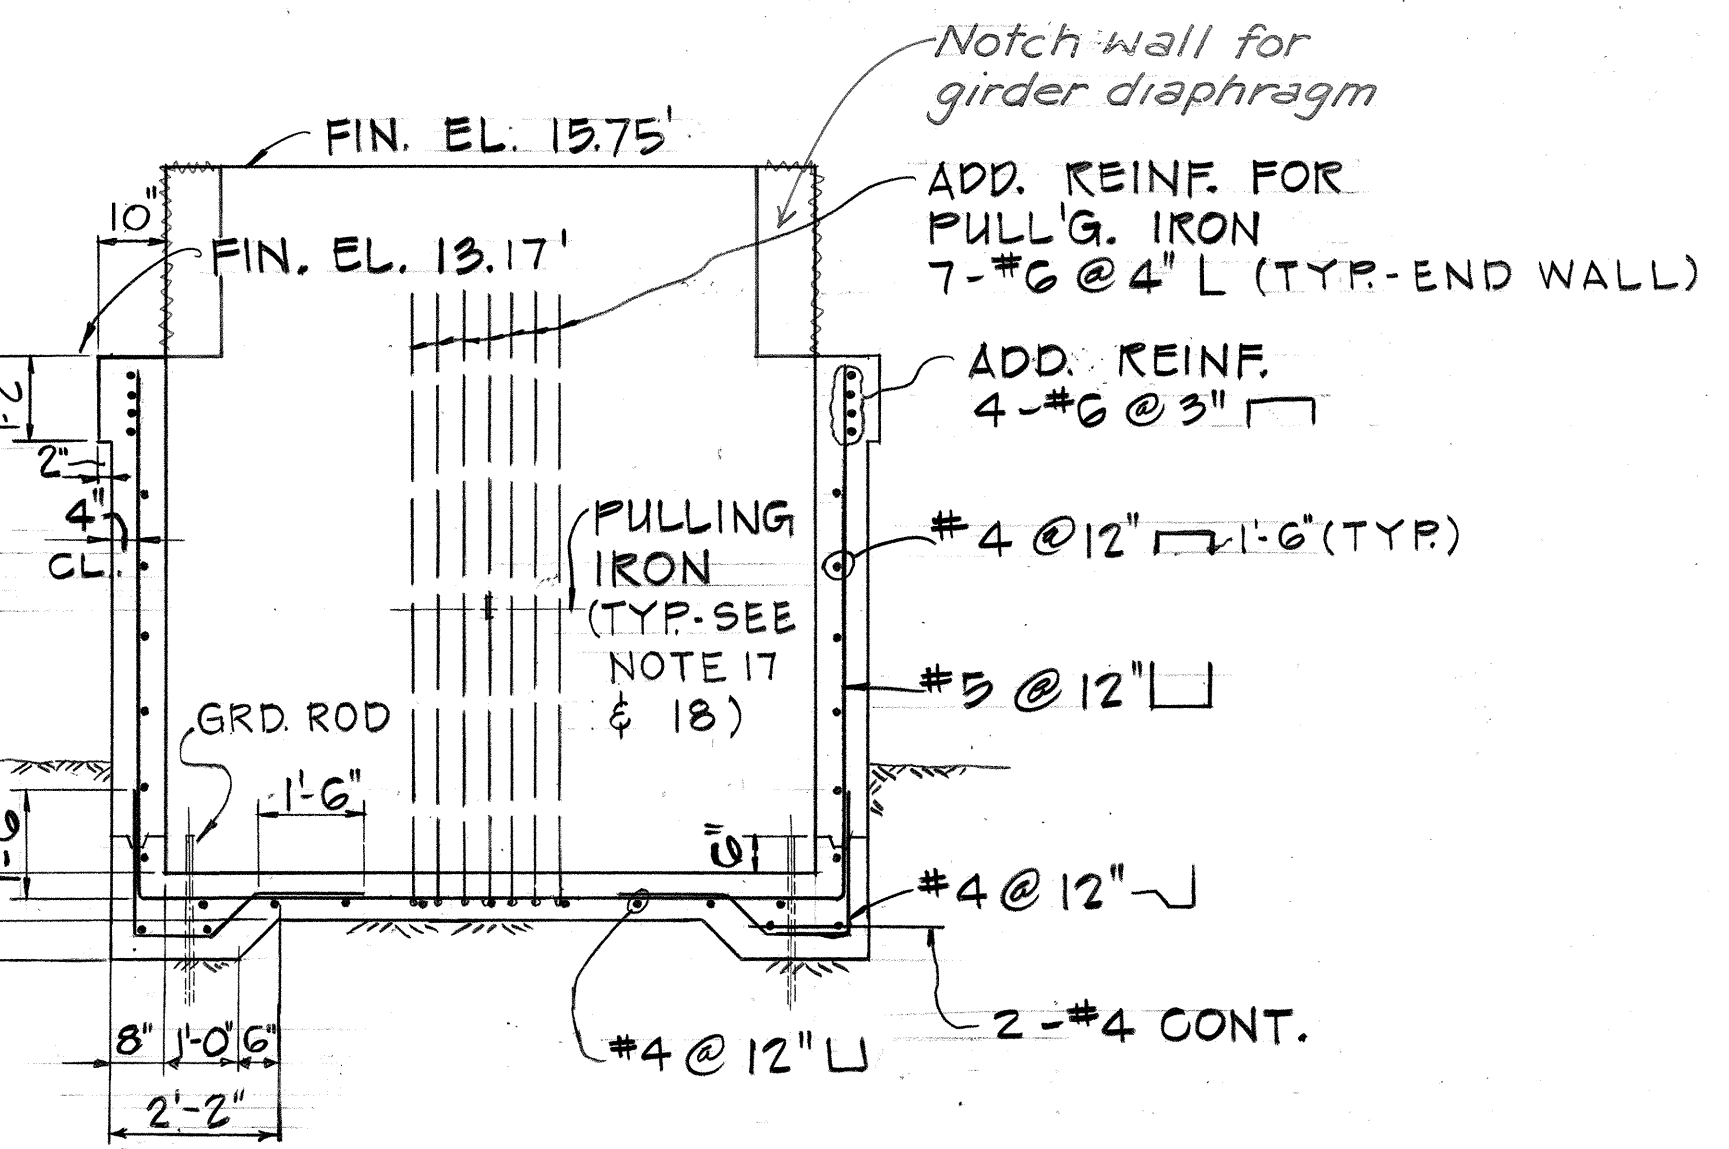


SECTION D
SCALE: 3/8"=1'-0"

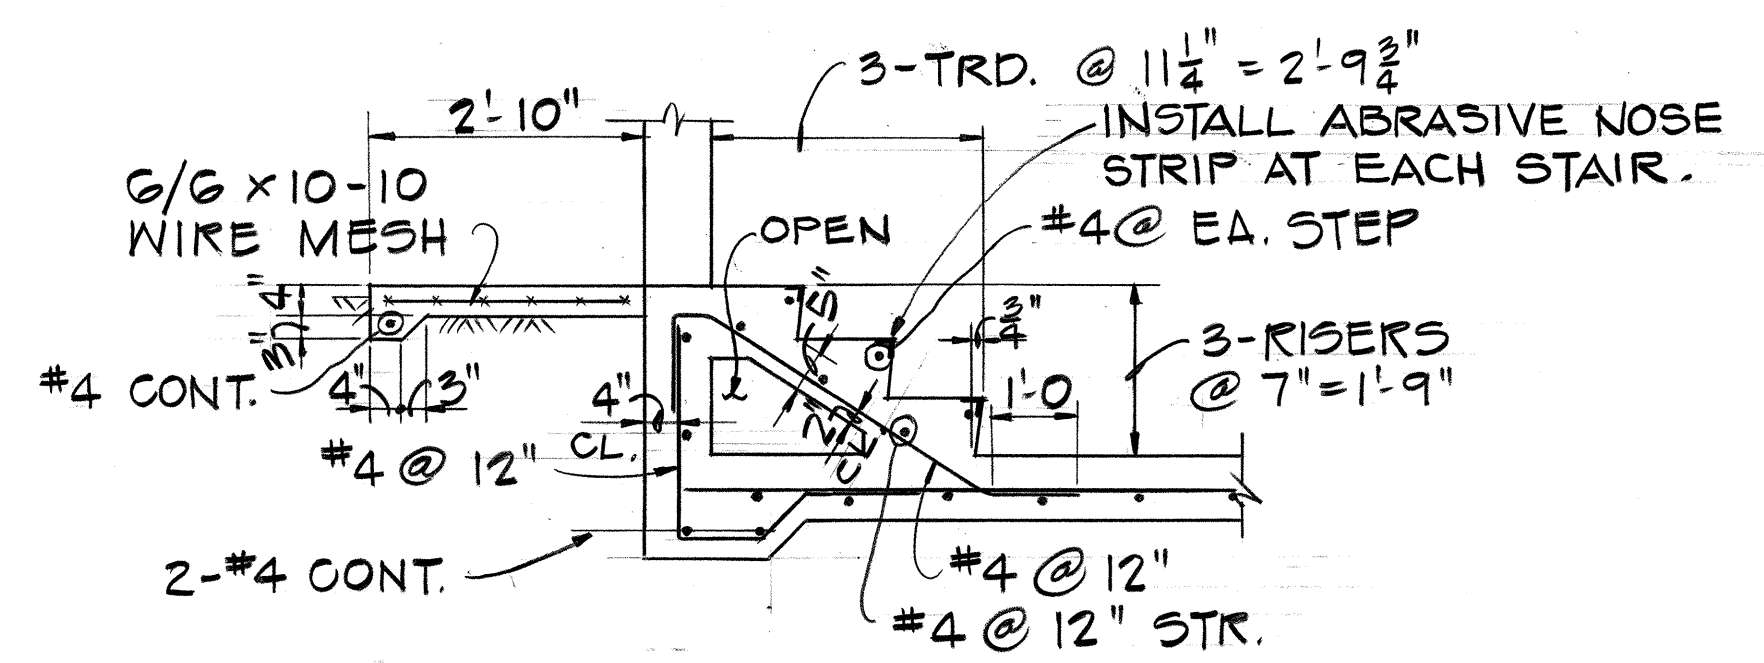

SECTION E
SCALE: 1/2"=1'-0"

QUANTITY OF MATERIALS	
CONCRETE	18.75 CU YD
REINFORCING	1580 LBS.
REINFORCING - ADDITIONAL (PULLING IRON ONLY - EA)	90 LBS. +
MISCELLANEOUS STEEL (PULLING IRON ONLY)	10.9 LBS.

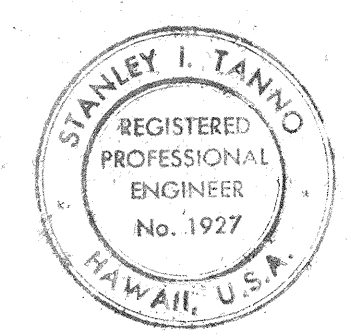

APPROVED
DATE
6-2-77
6-7-77
HAWAIIAN ELECTRIC COMPANY, INC.


HECO, INC. DRAWING NUMBER
2 3 3 5 0
STATE OF HAWAII
DEPARTMENT OF TRANSPORTATION
HIGHWAYS DIVISION
ELECTRIC HANDHOLE 'B'
INTERSTATE ROUTE H-1
PROJECT NO. I-H1-1(131)17
SCALE: AS NOTED
DATE: AUG. 31, 77
SHEET NO. U-7 OF U-23 SHEETS

179

SURVEY PLOTTED BY	DATE
DESIGNED BY	
CHECKED BY	
ORIGINAL PLAN	
NOTE BOOK	
QUANTITIES BY	
CHECKED BY	

FED. ROAD DIST. NO.	STATE	FED. AID PROJ. NO.	FISCAL YEAR	SHEET NO.	TOTAL SHEETS
HAWAII	HAW.	IHH(131)17	1977	180	394

- NOTES:**
- FOR GENERAL NOTES, SEE SHEET NO. 173
 - CAST IRON FRAME AND COVER HAVE TO BE PAINTED WITH ASPHALTUM PAINT FOR CORROSION PREVENTION.

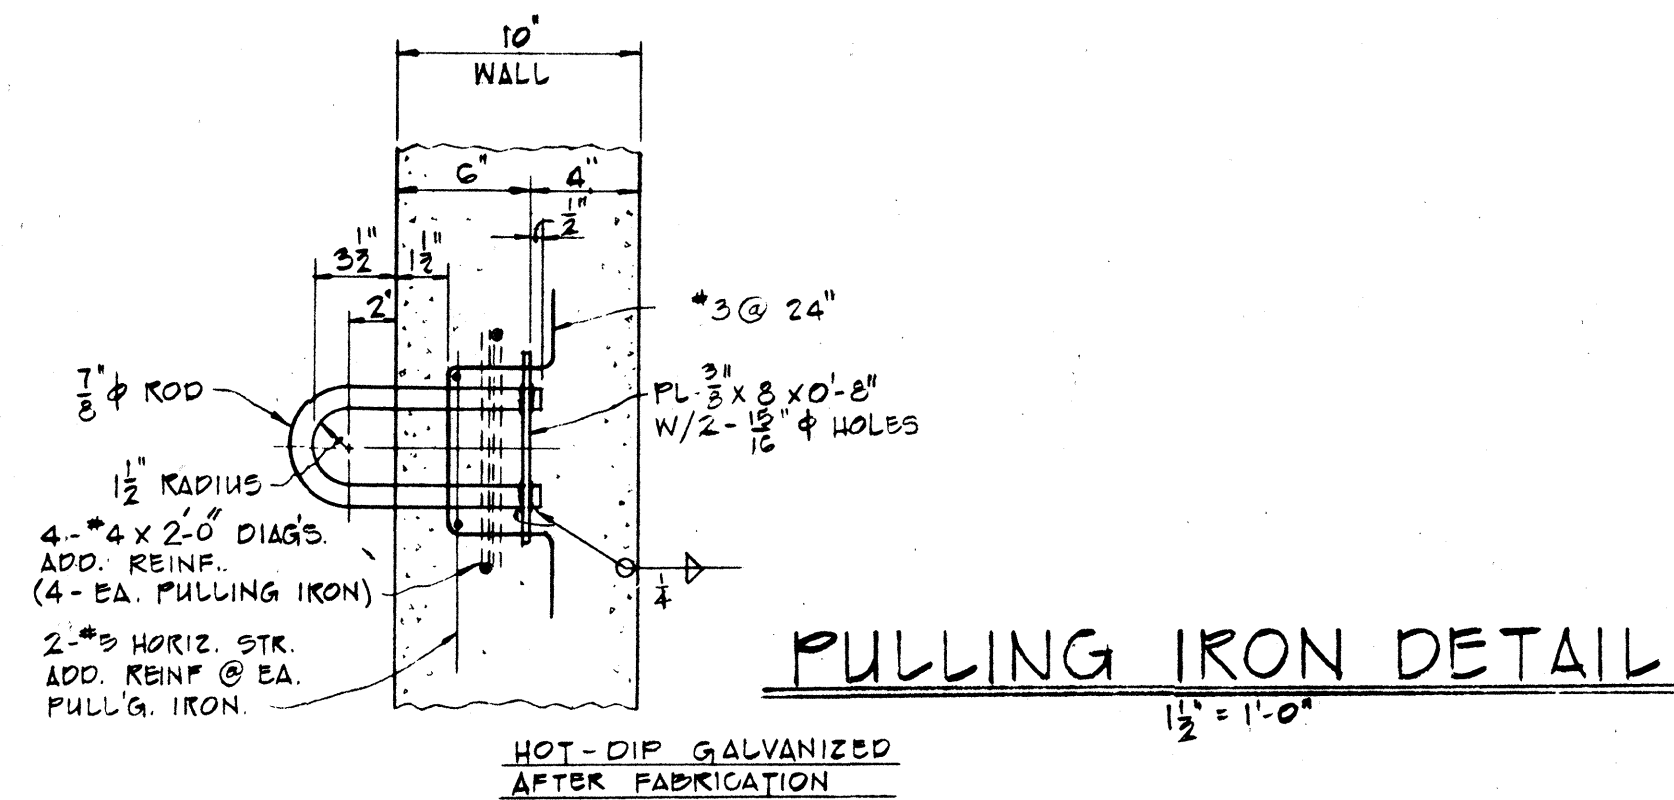

- REFERENCE DRAWINGS (HECO)**
- CS-7001- CONSTRUCTION OF UNDERGROUND FACILITIES (6 SHEETS) SPECIFICATION SHEET
 - CS-7003- CONSTRUCTION OF ELECTRICAL FACILITIES (4 SHEETS) SPECIFICATION SHEET
 - O-11327 STANDARD HECO 31\" MANHOLE COVER
 - O-11328 STANDARD HECO 31\" MANHOLE FRAME
 - 16688-A MISCELLANEOUS DETAILS, MANHOLES & HANDHOLES

QUANTITY OF MATERIALS (M.H. ONLY)

CONCRETE	22.80 CY
REINFORCING	2977 LBS
MISC STEEL (PULLG IRONS, EA.)	10.9 LBS

ADDITIONAL QUANTITY OF MATERIALS FOR ALTERNATE M.H. NECK (DIMENSION 'X' = 2'-0')

CONCRETE	0.50 CY
REINFORCING	42 21 LBS






APPROVED:

HAWAIIAN ELECTRIC CO., LTD.

8/10/77
DATE


STATE OF HAWAII
DEPARTMENT OF TRANSPORTATION
HIGHWAYS DIVISION
ELECTRIC
MANHOLE TYPE #6
(8'-0" x 16'-0" x 6.5')
INTERSTATE ROUTE H-1
PROJECT NO. I-H1-1 (131) 17


SCALE: AS SHOWN
DATE: AUG. 31, 1977
SHEET No. U-8 OF U-23 SHEETS

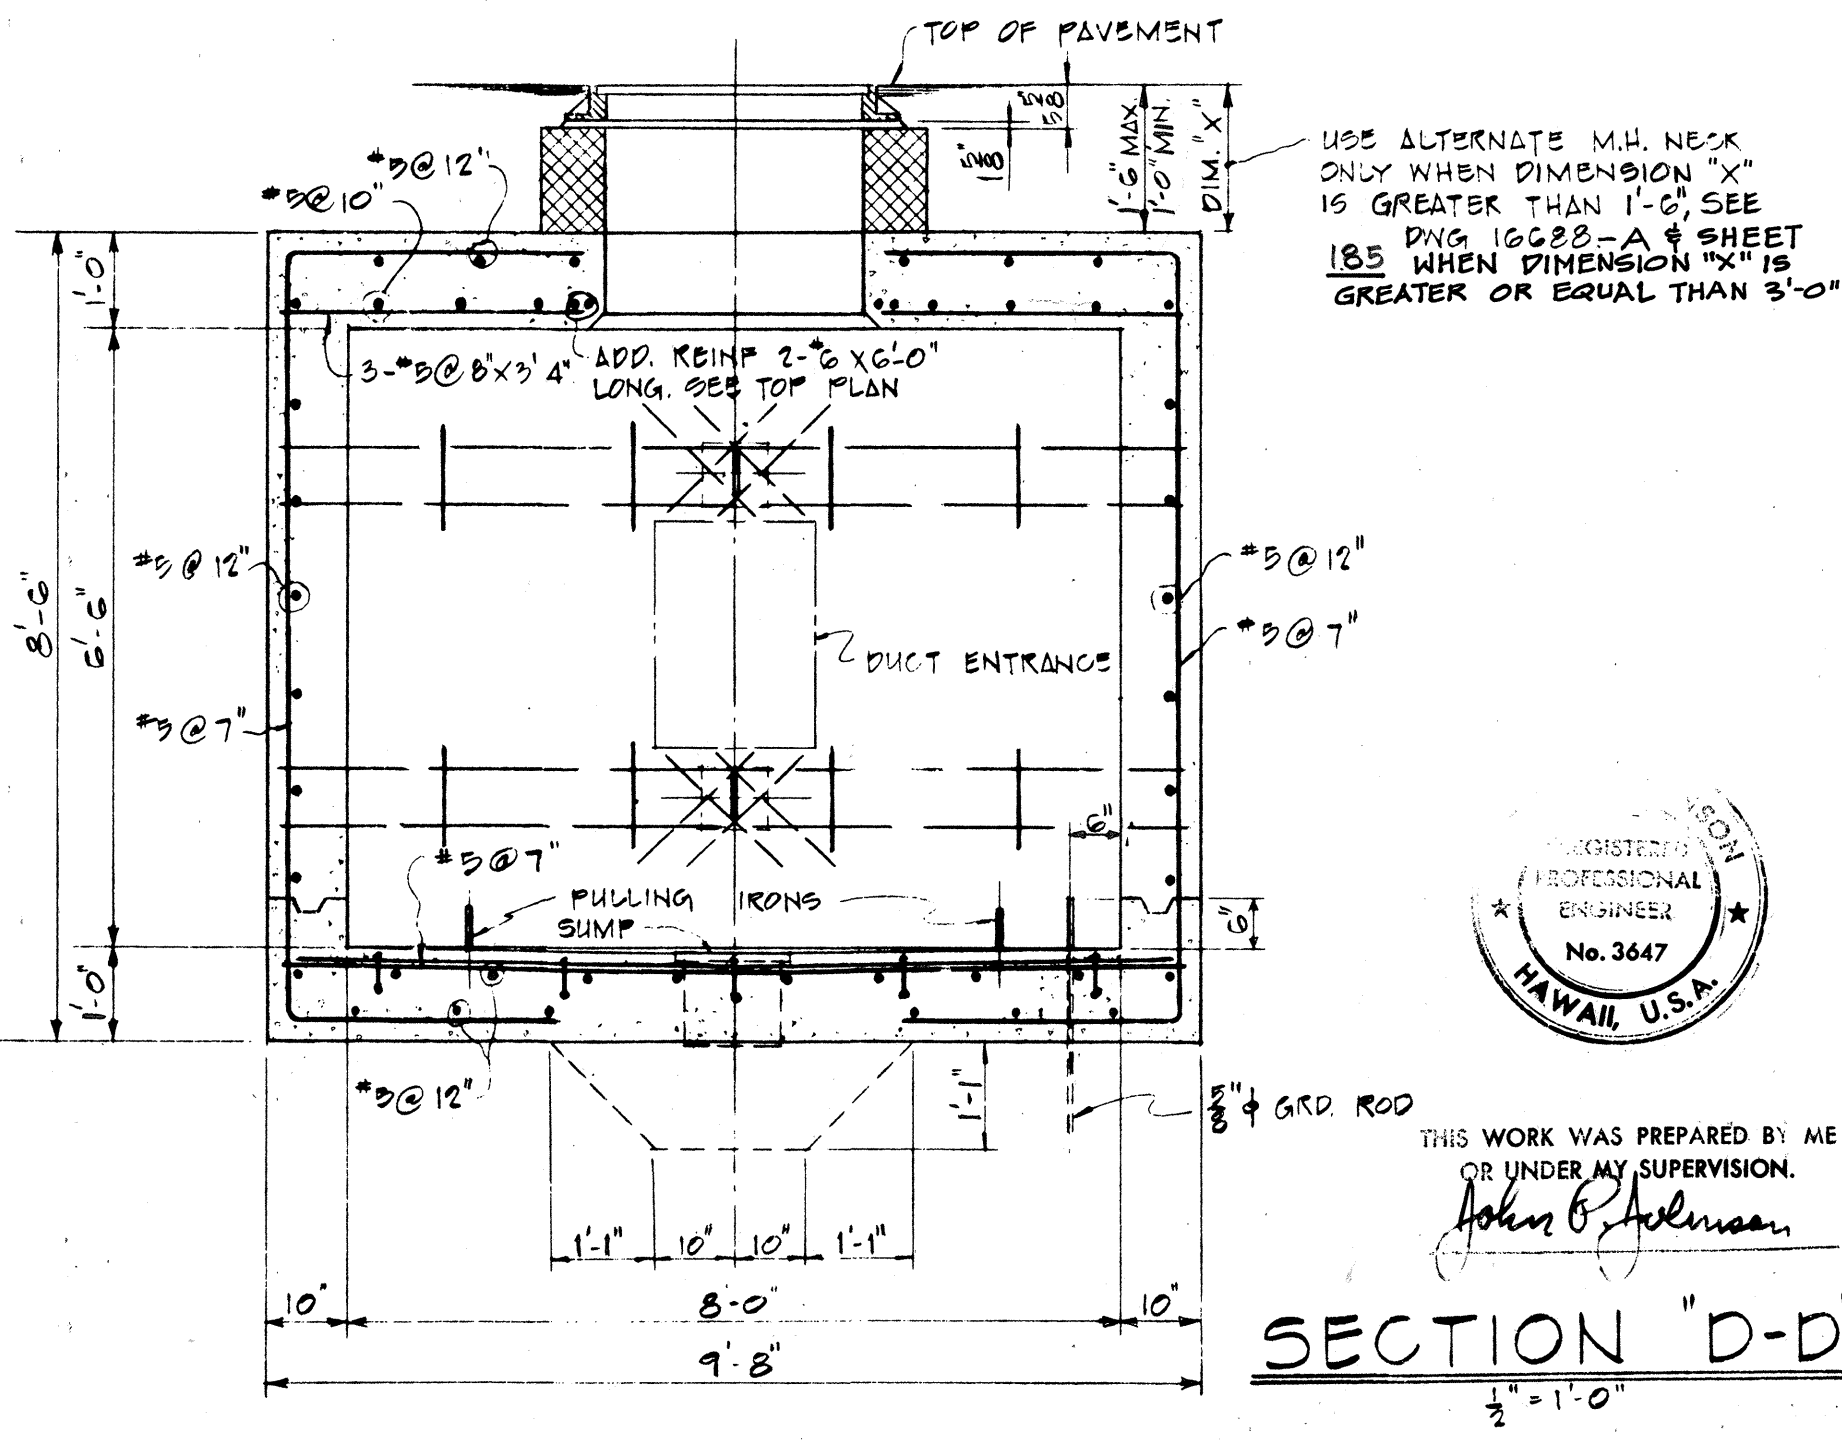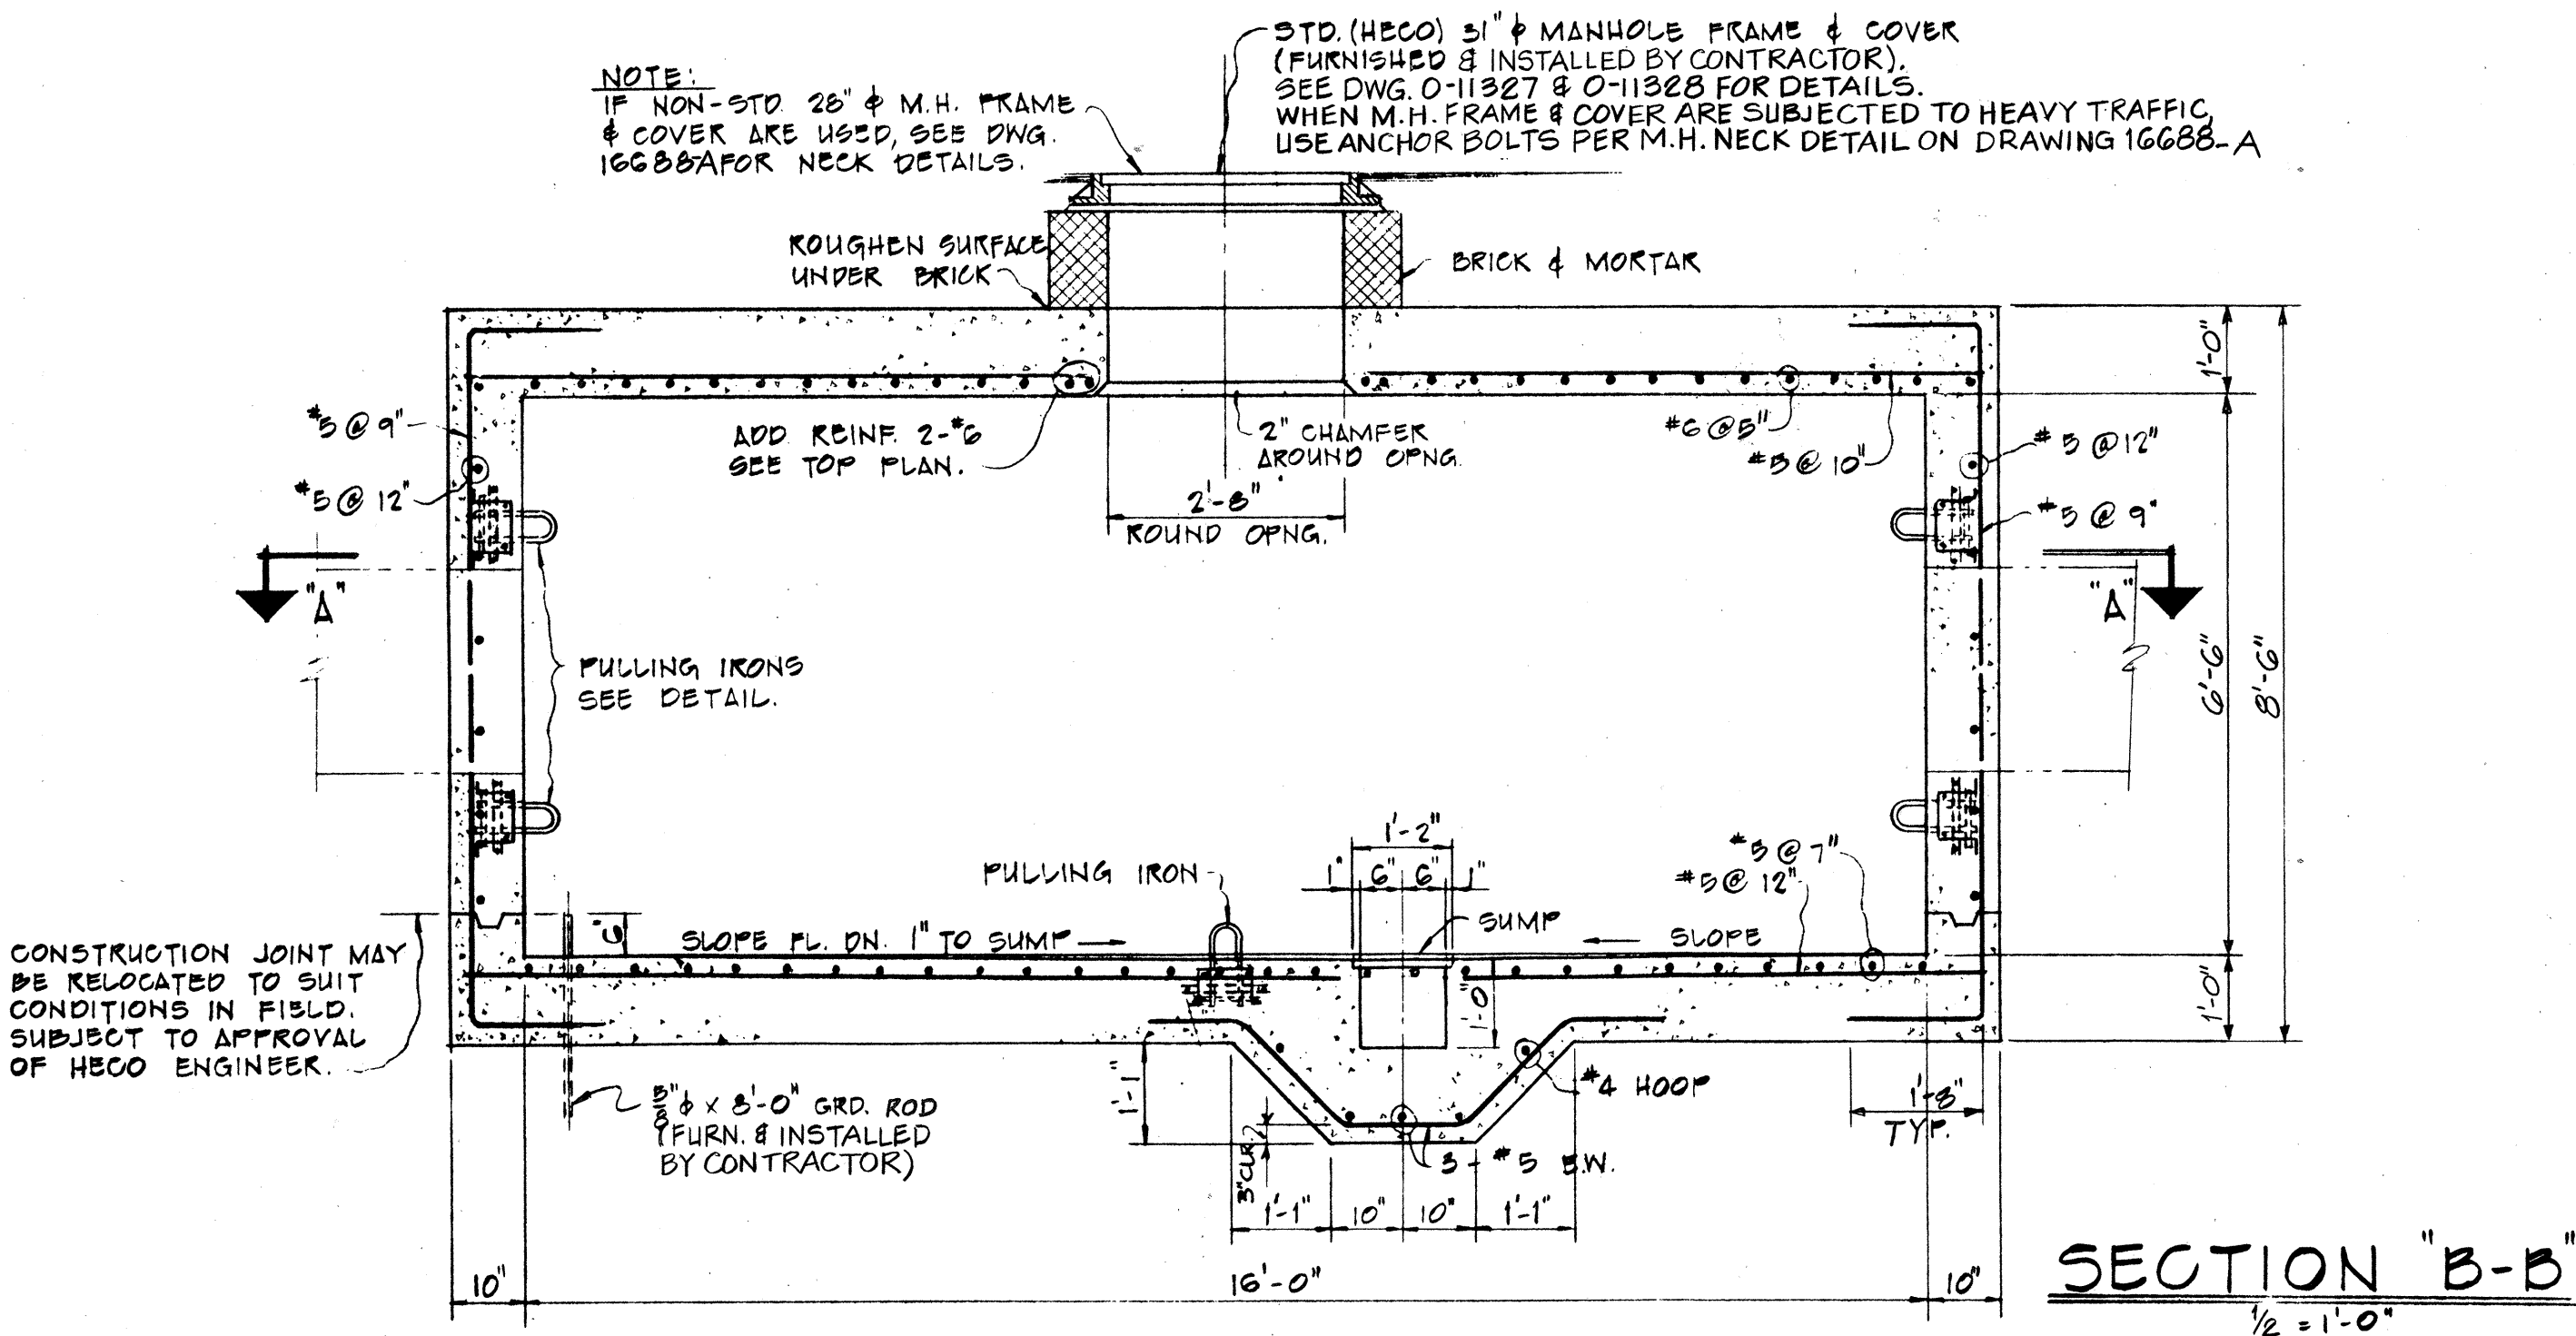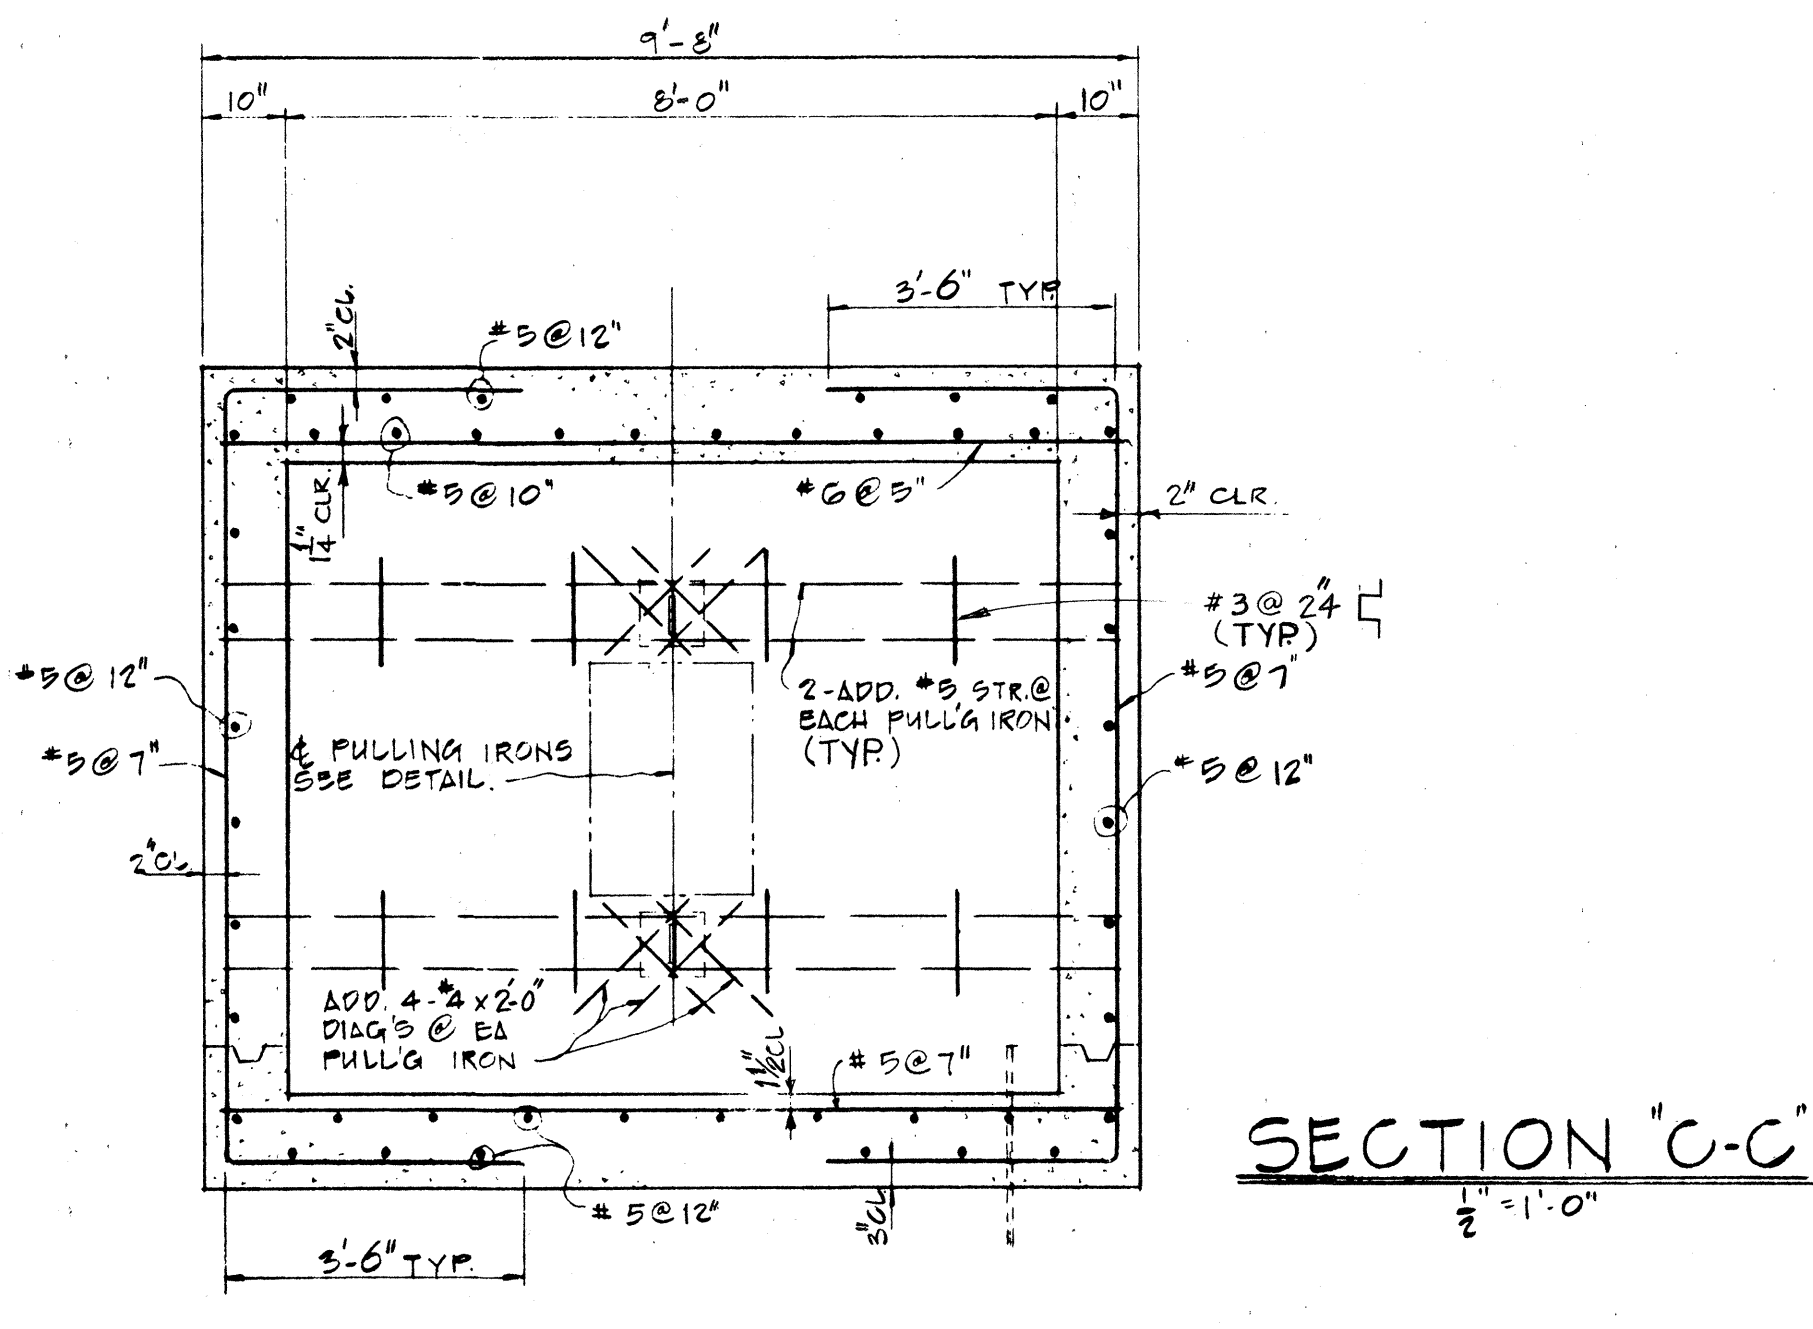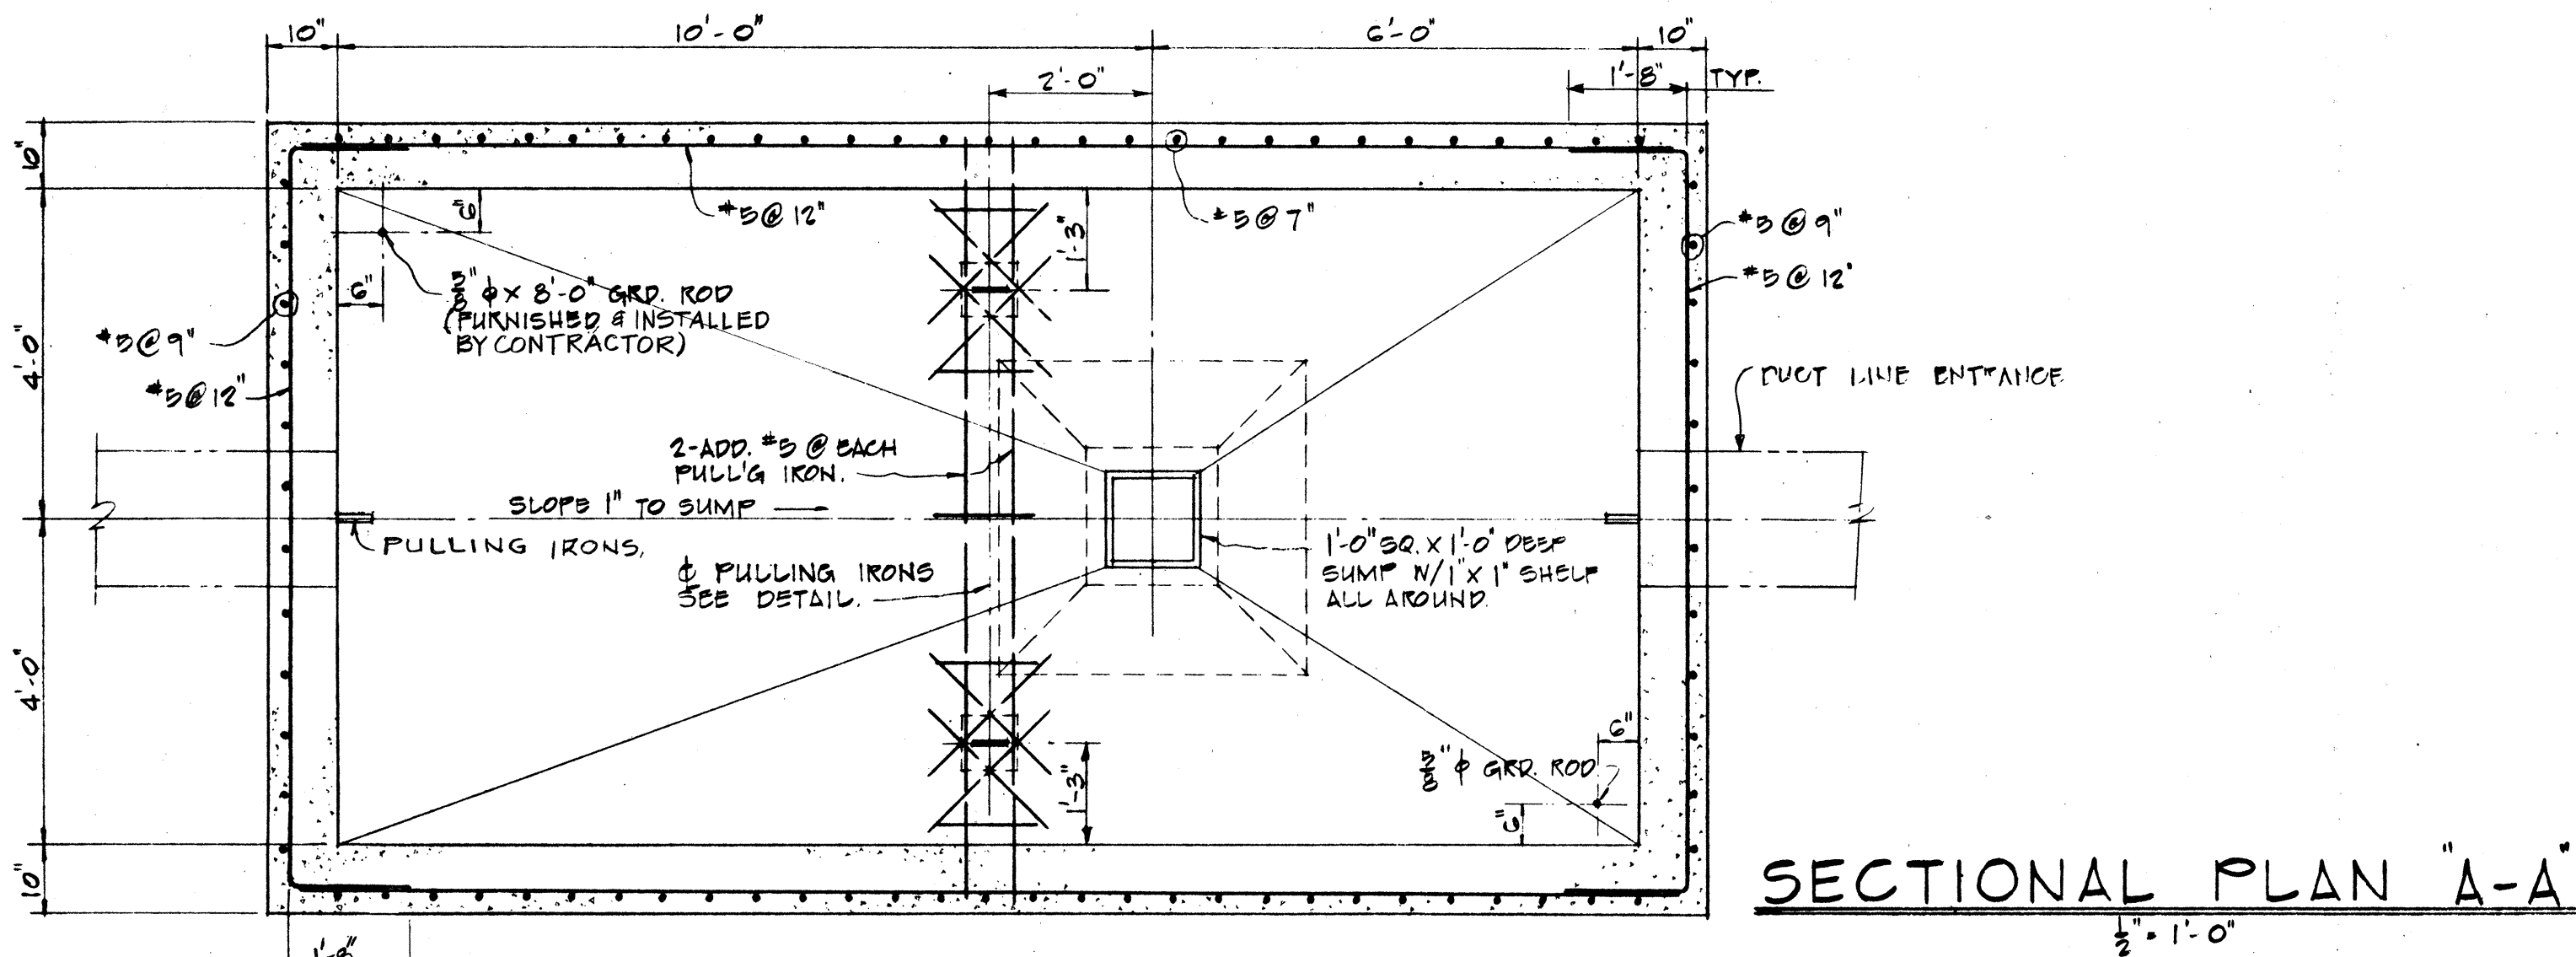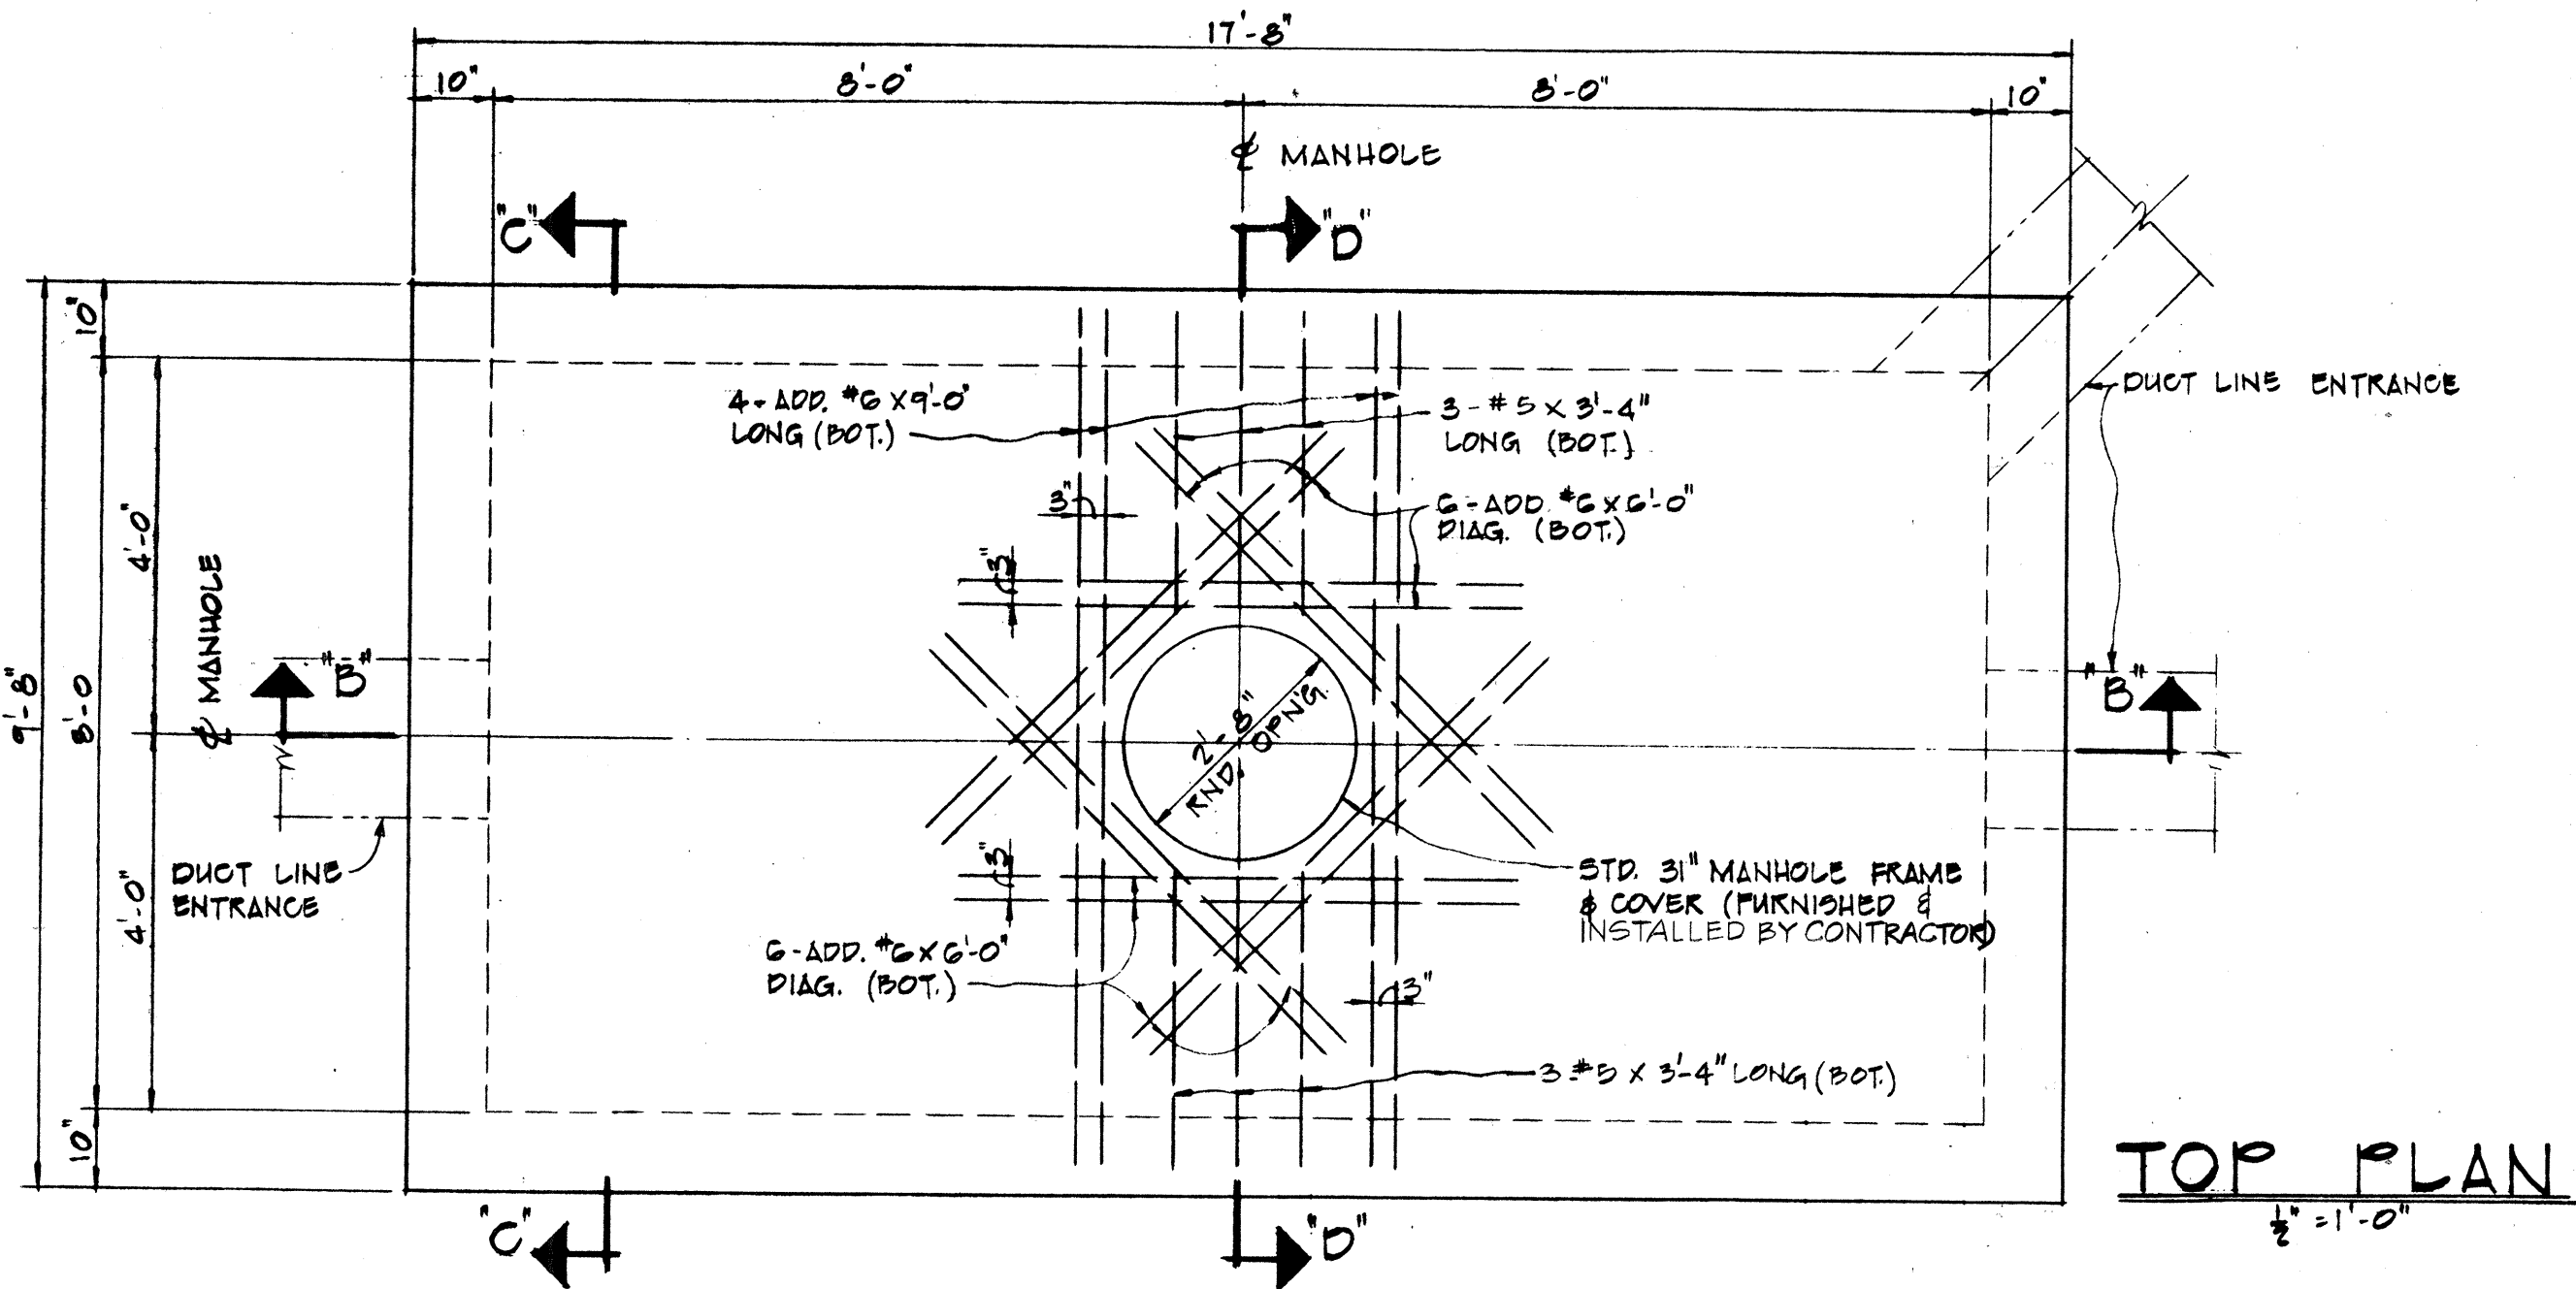


SURVEY PLOTTED BY
 DRAWN BY
 TRACED BY
 DESIGNED BY
 CHECKED BY
 NO.

 CONSTRUCTION JOINT MAY BE RELOCATED TO SUIT CONDITIONS IN FIELD. SUBJECT TO APPROVAL OF HECO ENGINEER.

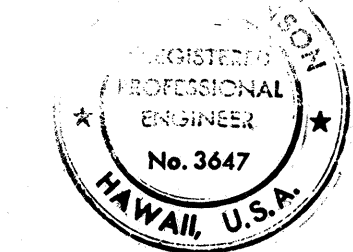


THIS WORK WAS PREPARED BY ME OR UNDER MY SUPERVISION.


FED. ROAD DIST. NO.	STATE	FED. AID PROJ. NO.	FISCAL YEAR	SHEET NO.	TOTAL SHEETS
HAWAII	HAW.	I-HI-1(131)17	1977	181	394

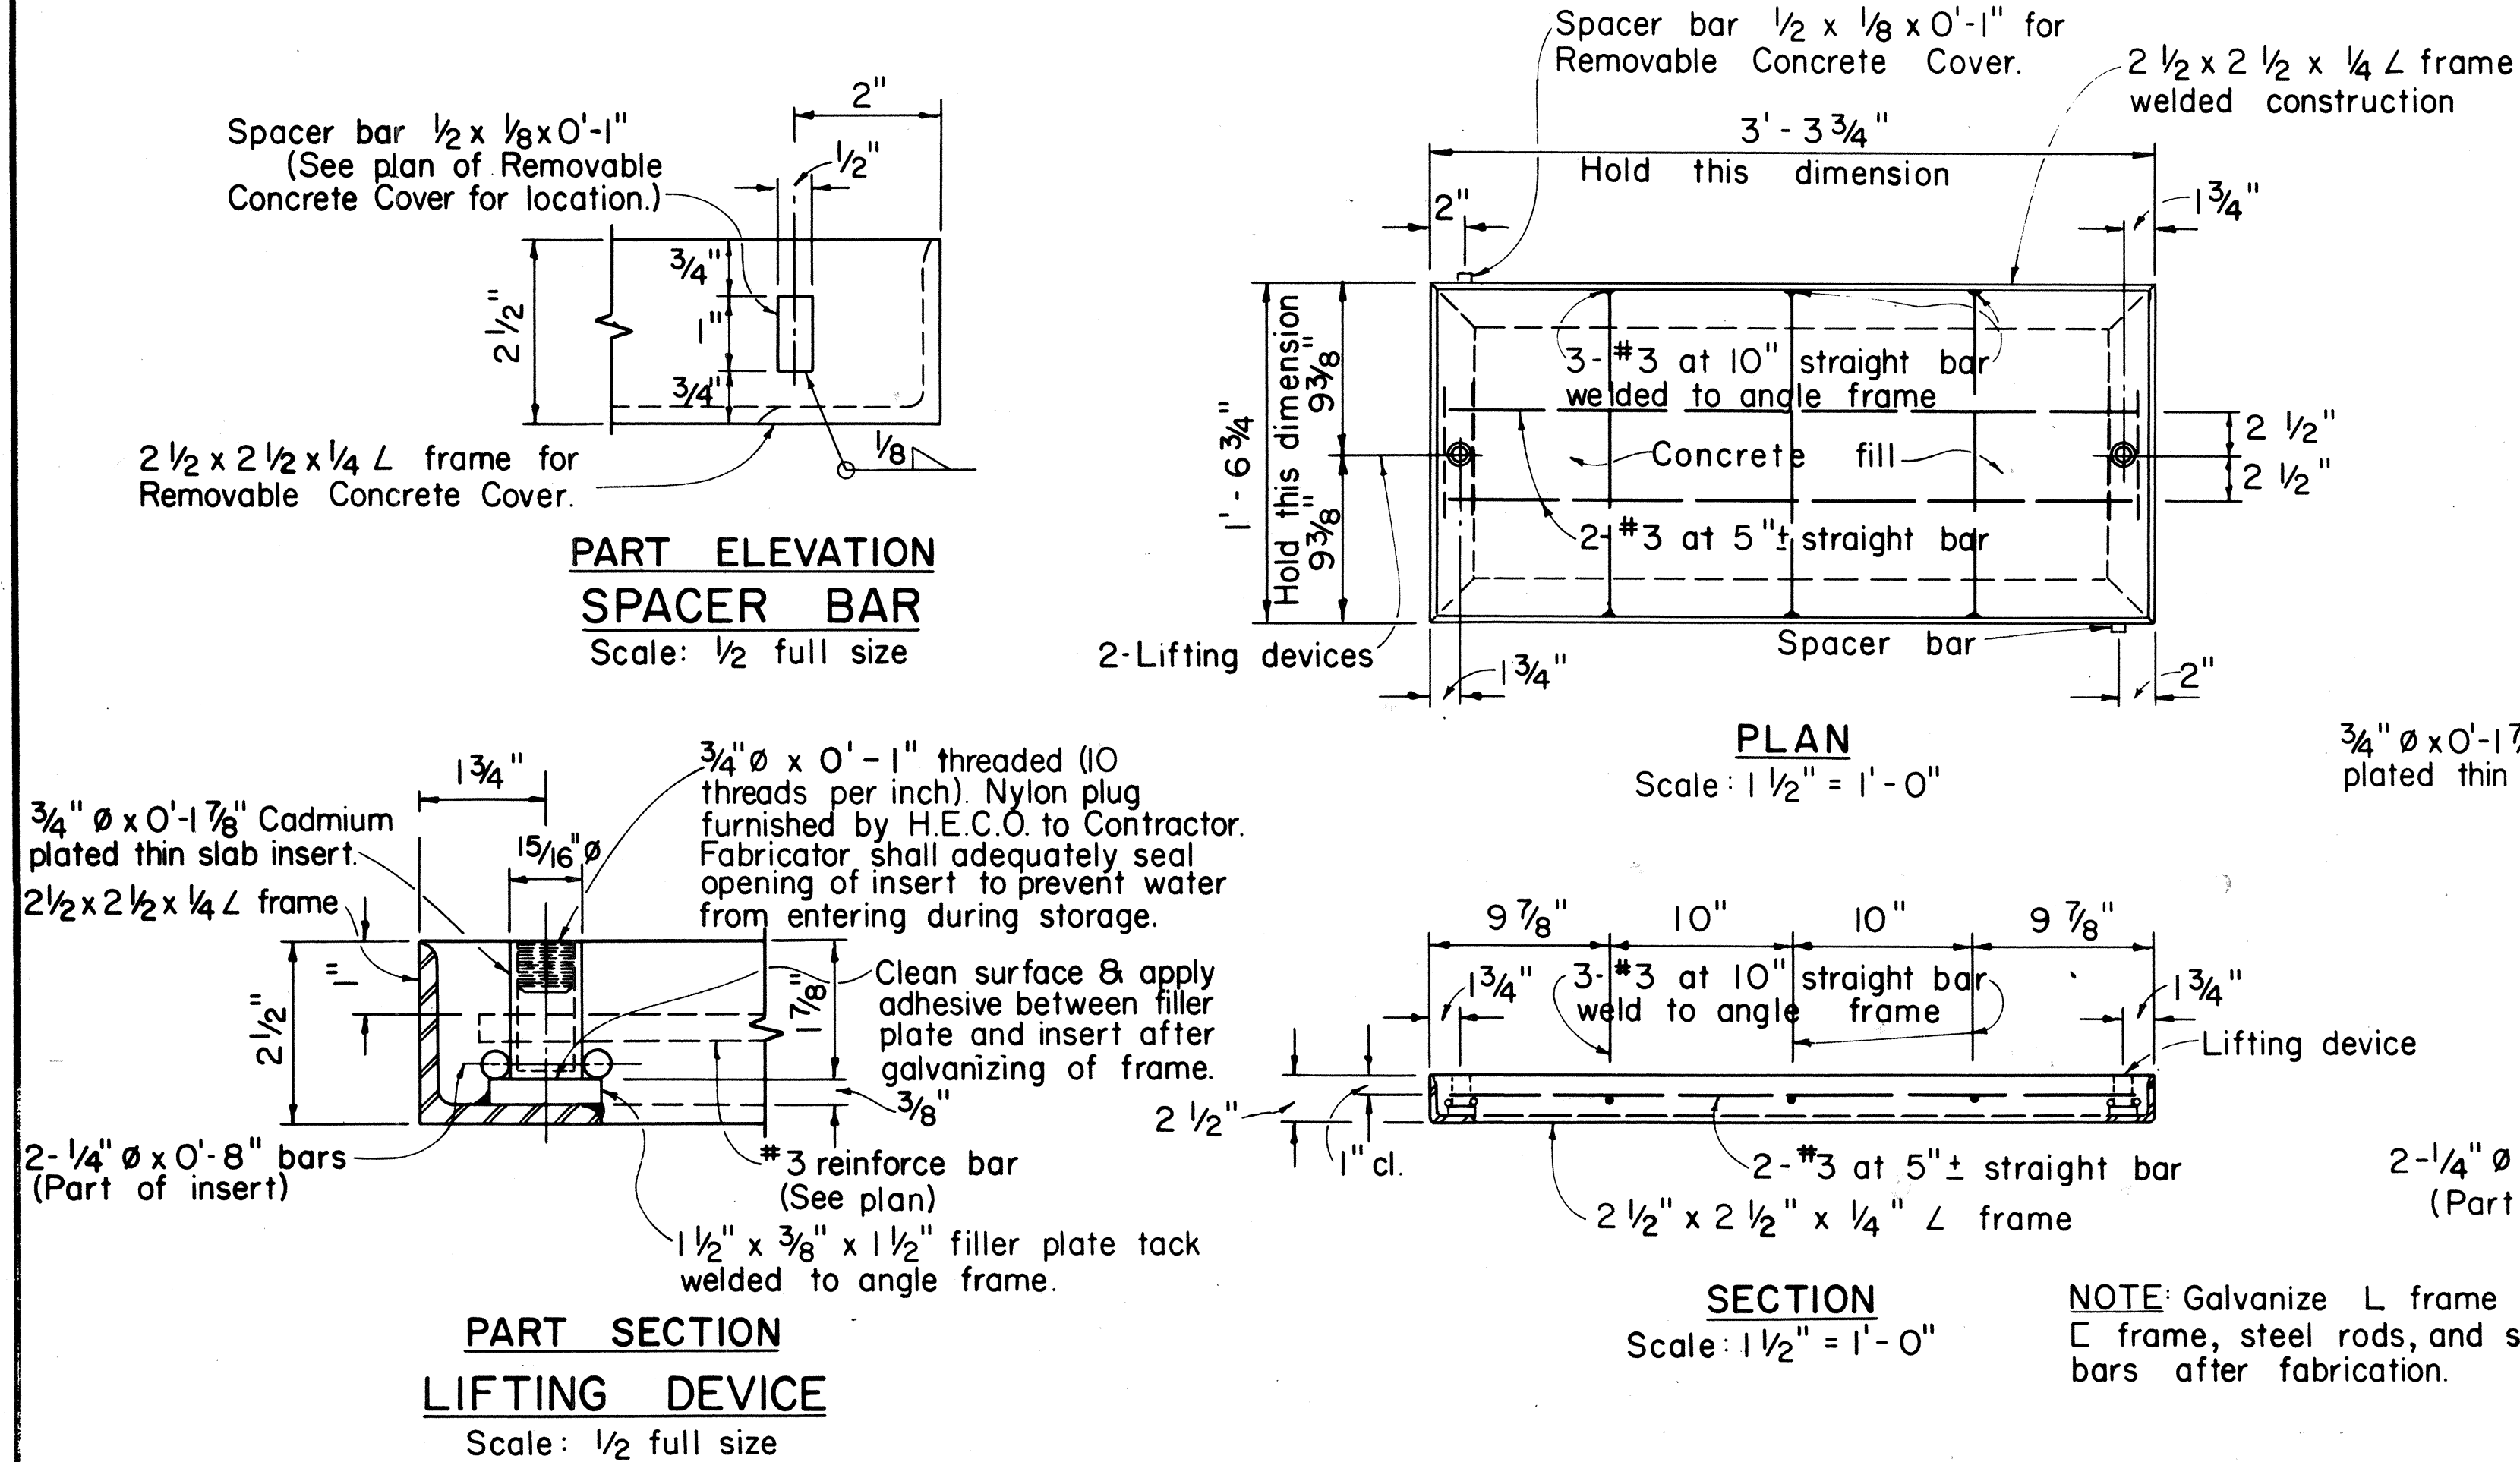


TYPE "SW" REMOVABLE CONCRETE COVER

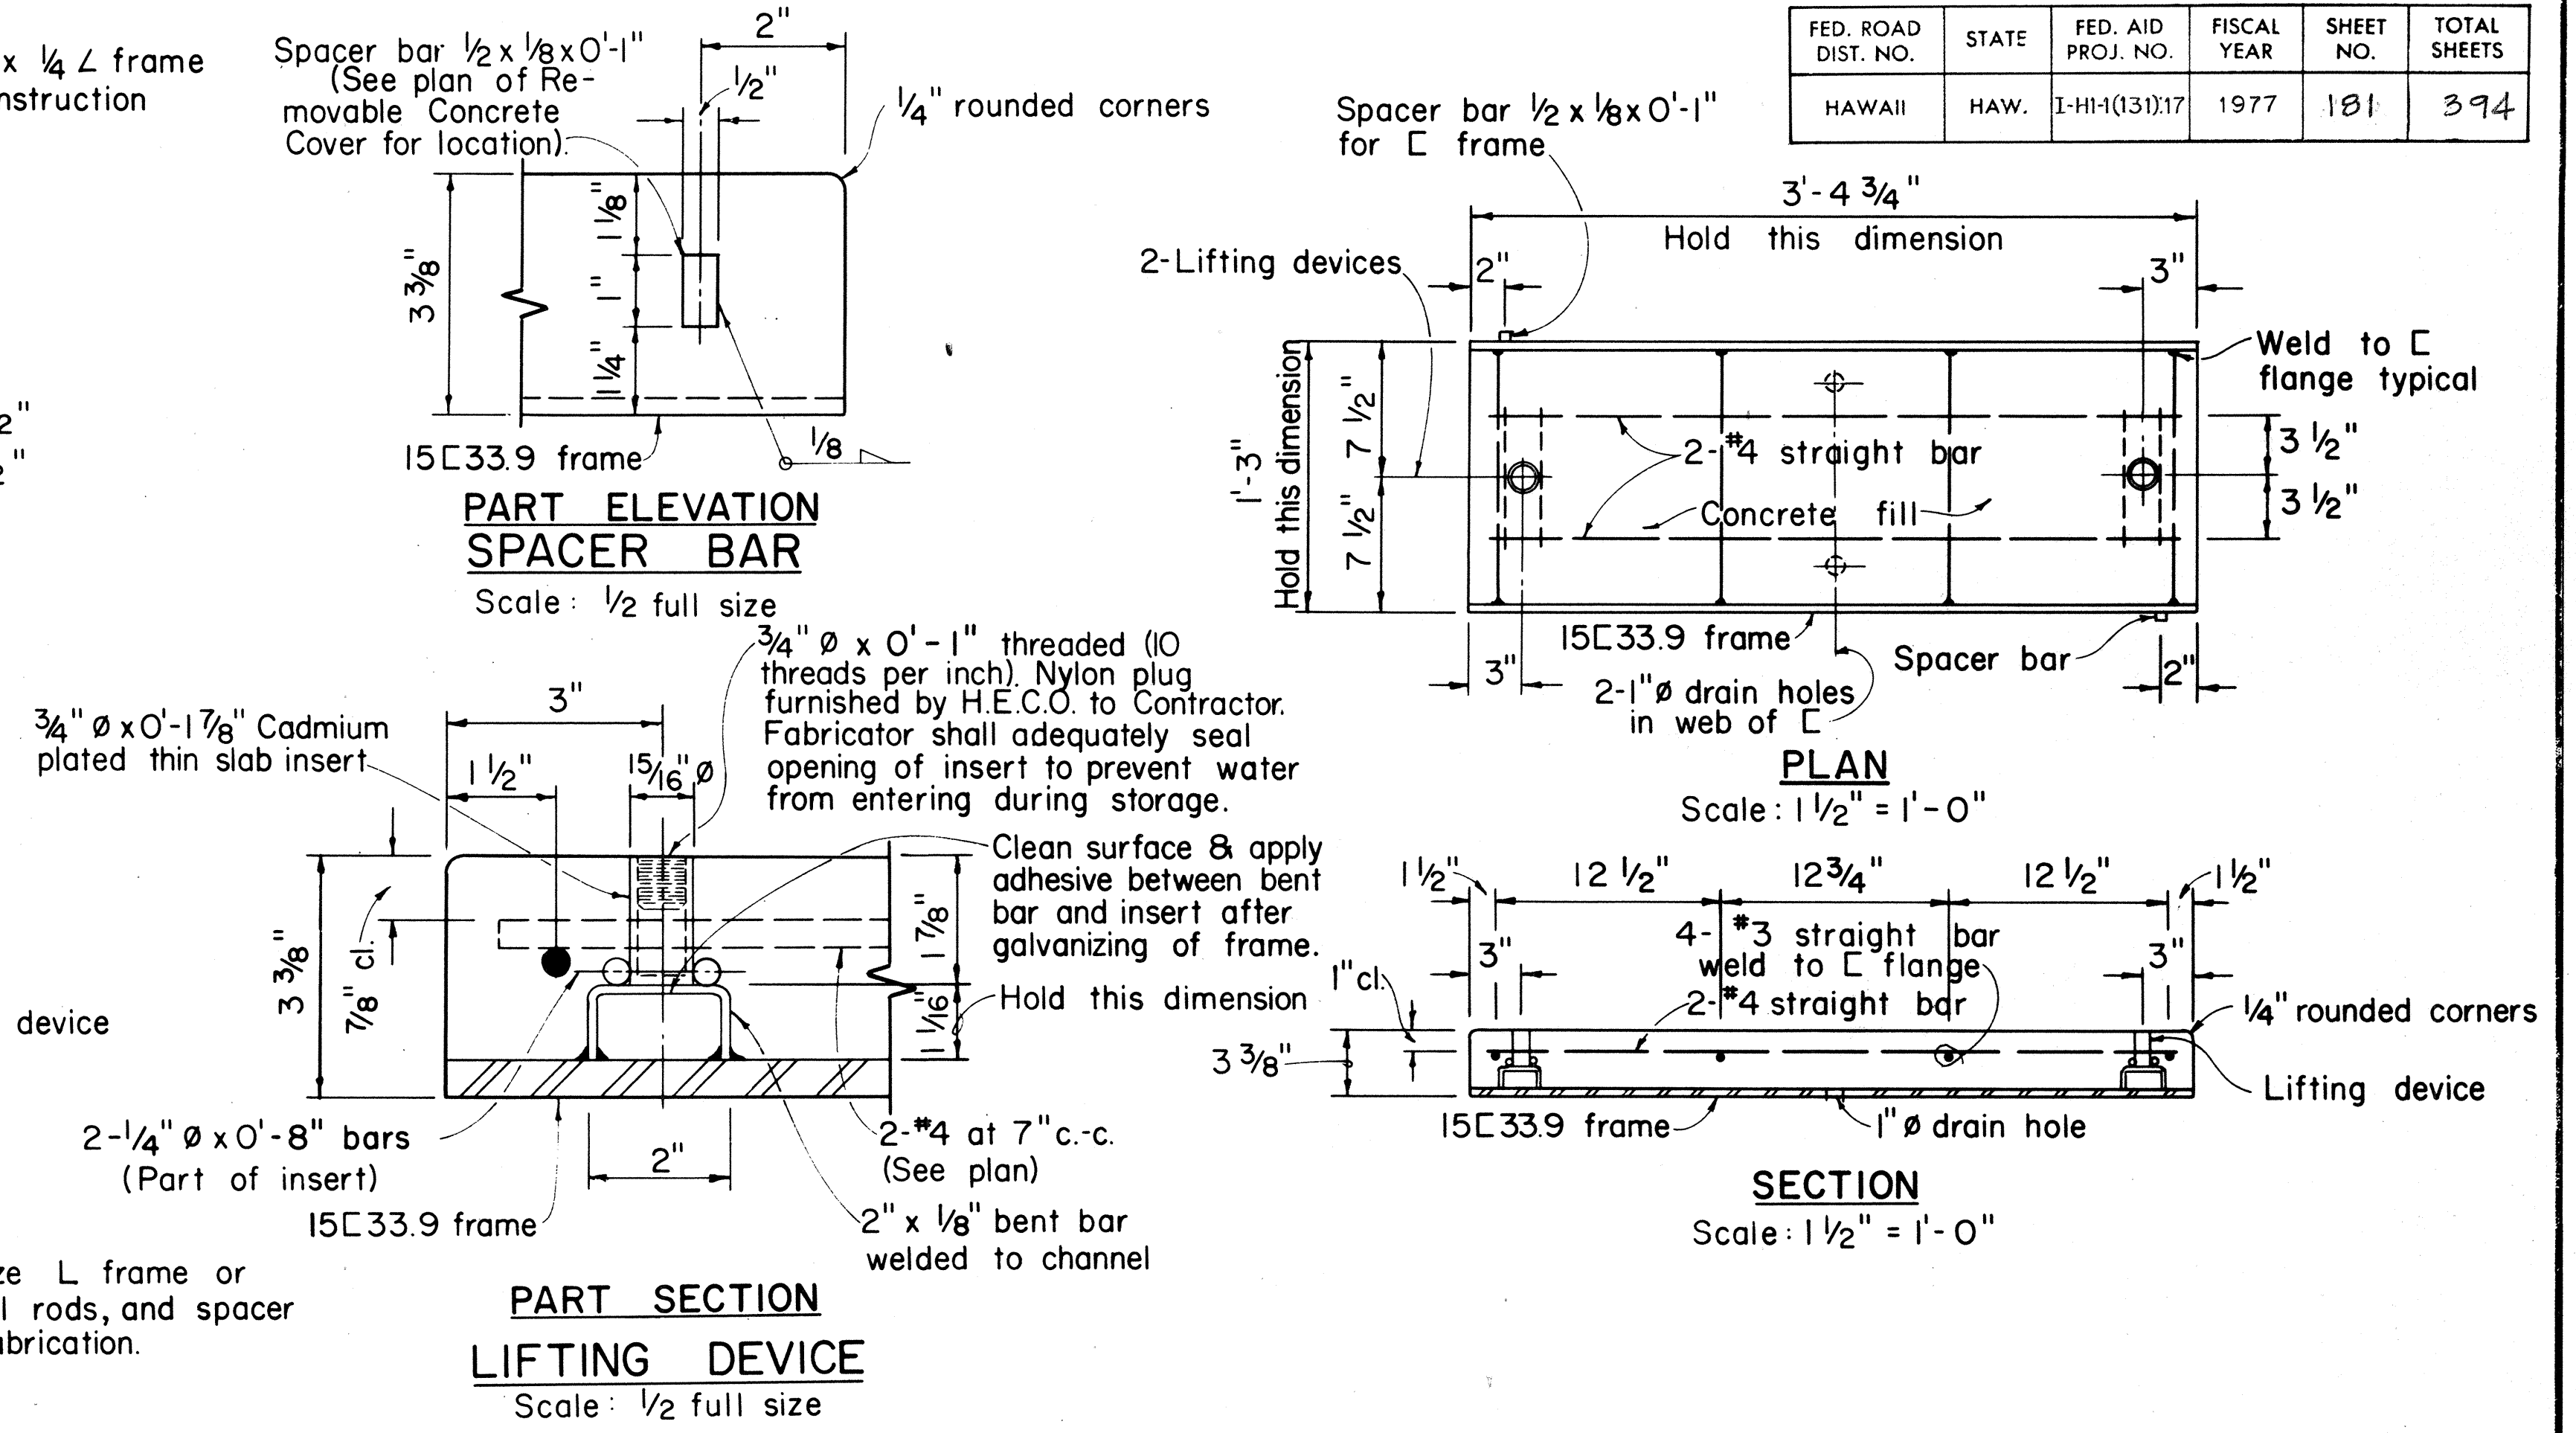

TYPE "TR" REMOVABLE CONCRETE COVER


GENERAL NOTES

- On handhole covers, maximum clearances must be kept between removable concrete cover slabs and concrete openings at the supports. Contractor shall measure cover slabs steel frame after fabrication to obtain proper clearances. All covers after being installed shall be seated firmly and evenly and be free from rocking. Any variation in clearances and unevenness shall be corrected to the satisfaction of the Engineer at the Contractor's expense.
- Concrete Pouring: Notify the Hawaiian Electric Co., Inc. Contracting & Inspection Division, 24 hours before pouring concrete. All concrete pouring shall be done in the presence of a Hawaiian Electric Co., Inc. Engineer or Inspector.
- All materials shall be new and manufactured in the United States of America.

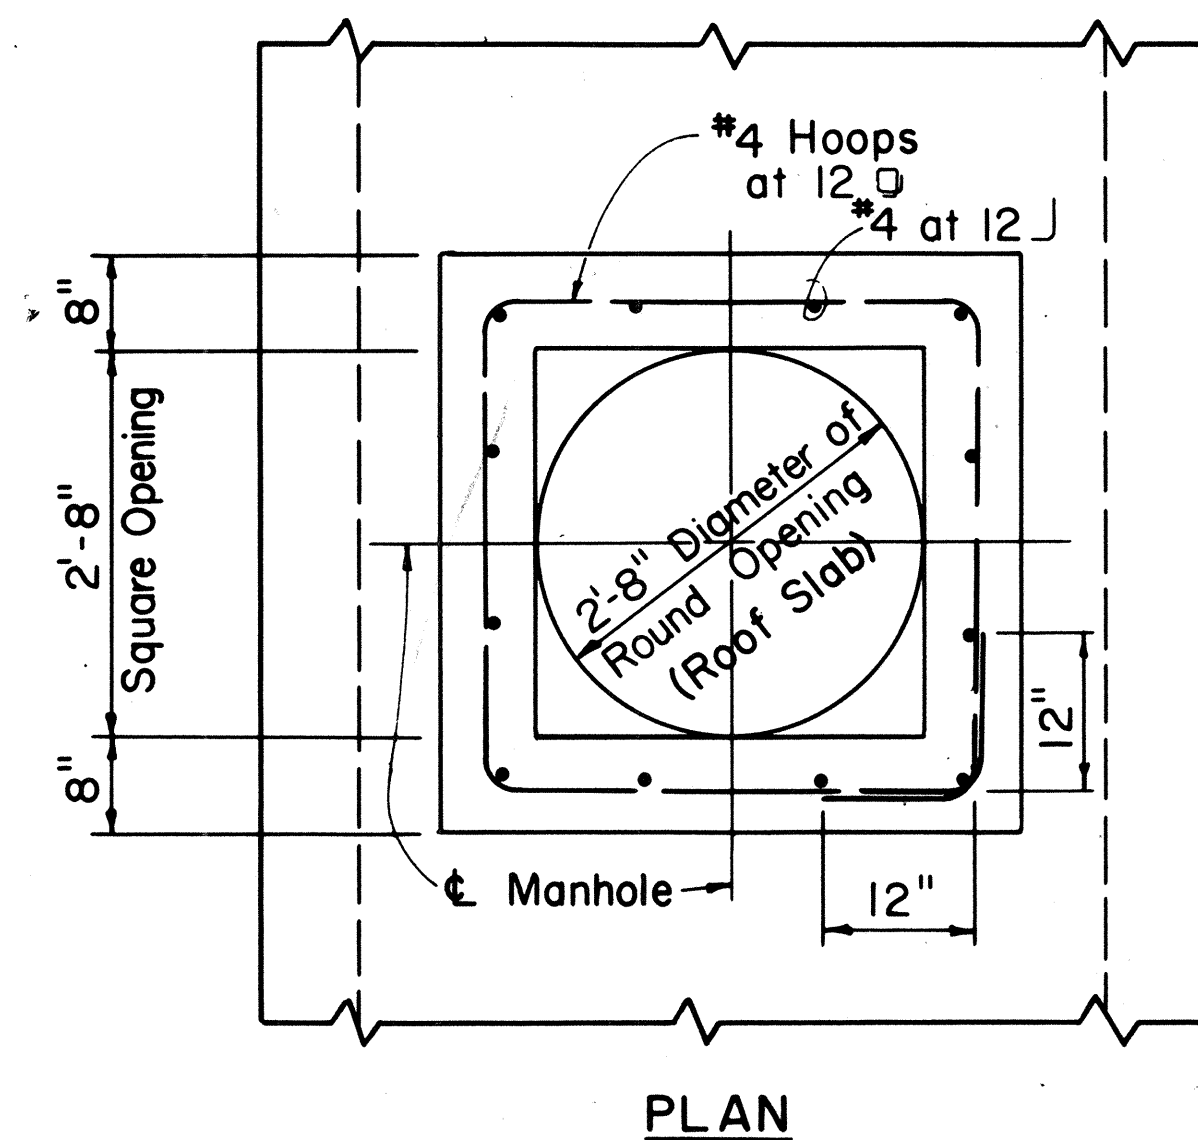

ALTERNATE MANHOLE NECK

Scale: 3/4" = 1' - 0"

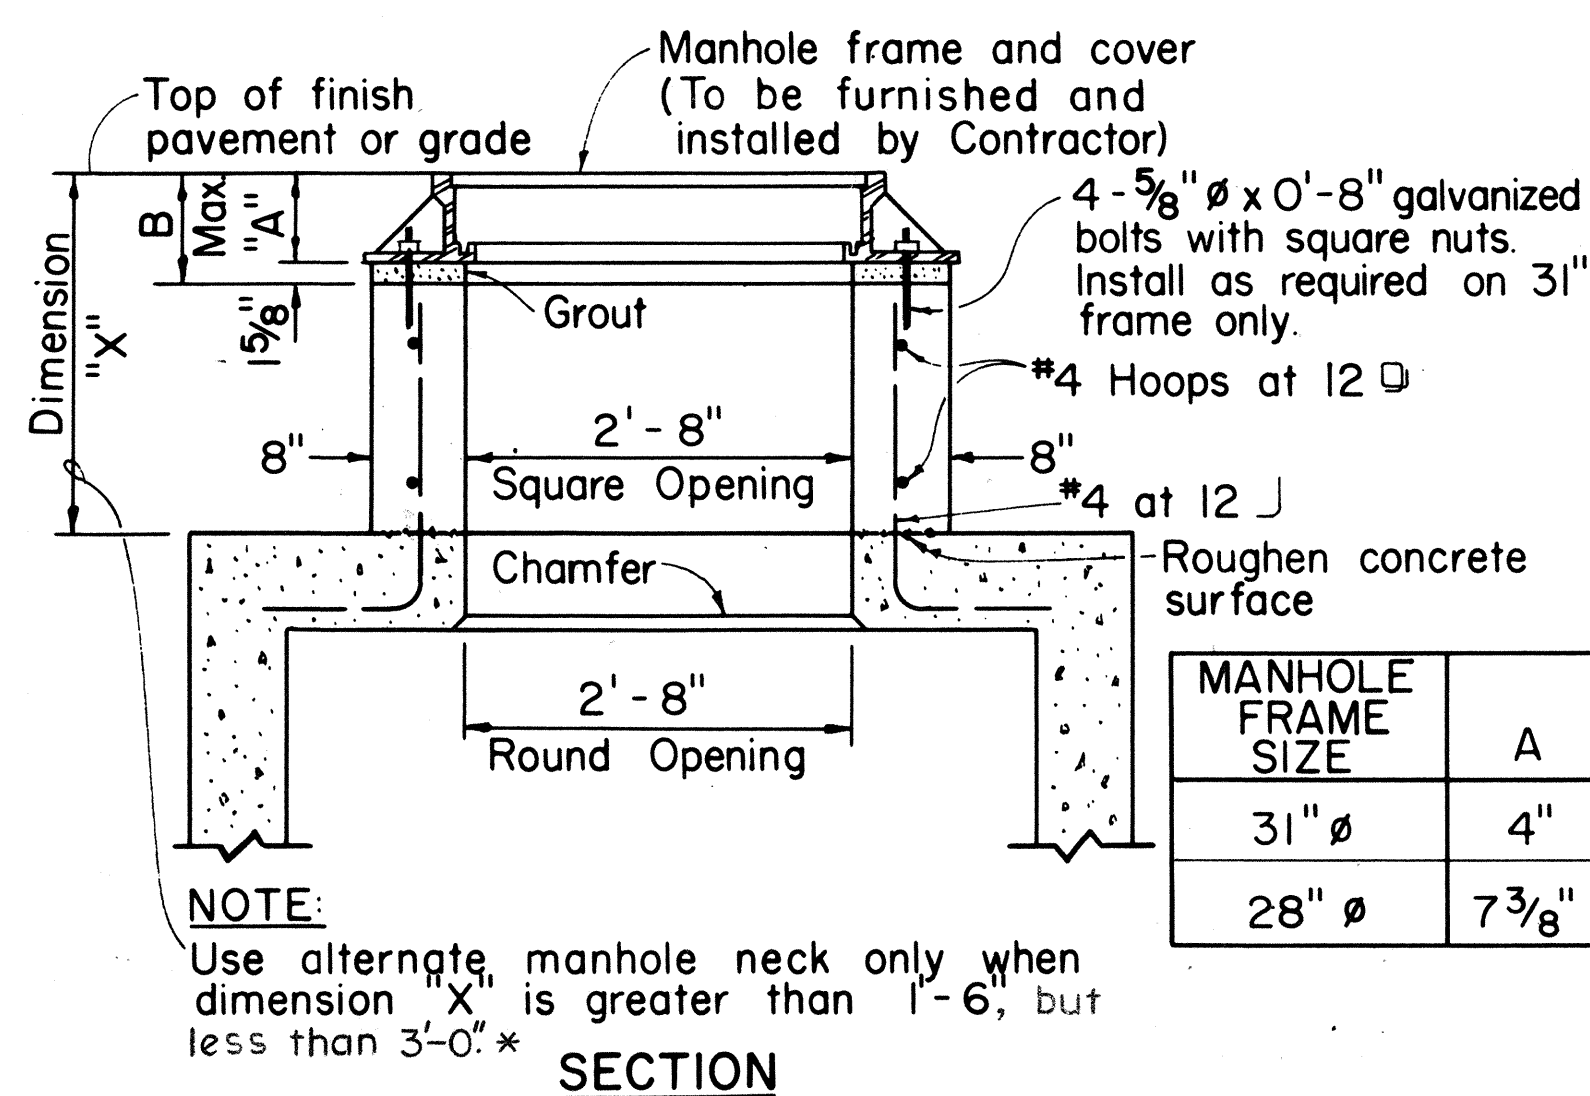

NOTE: Use alternate manhole neck only when dimension X is greater than 1'-6", but less than 3'-0".


SECTION

MANHOLE FRAME SIZE	A	B
31" Ø	4"	5 5/8"
28" Ø	7 3/8"	9"

* For "X" equal or greater than 3'-0" see Sheet 186

31" Ø & 28" Ø MANHOLE FRAME NECK DETAIL

Scale: 3/4" = 1' - 0"

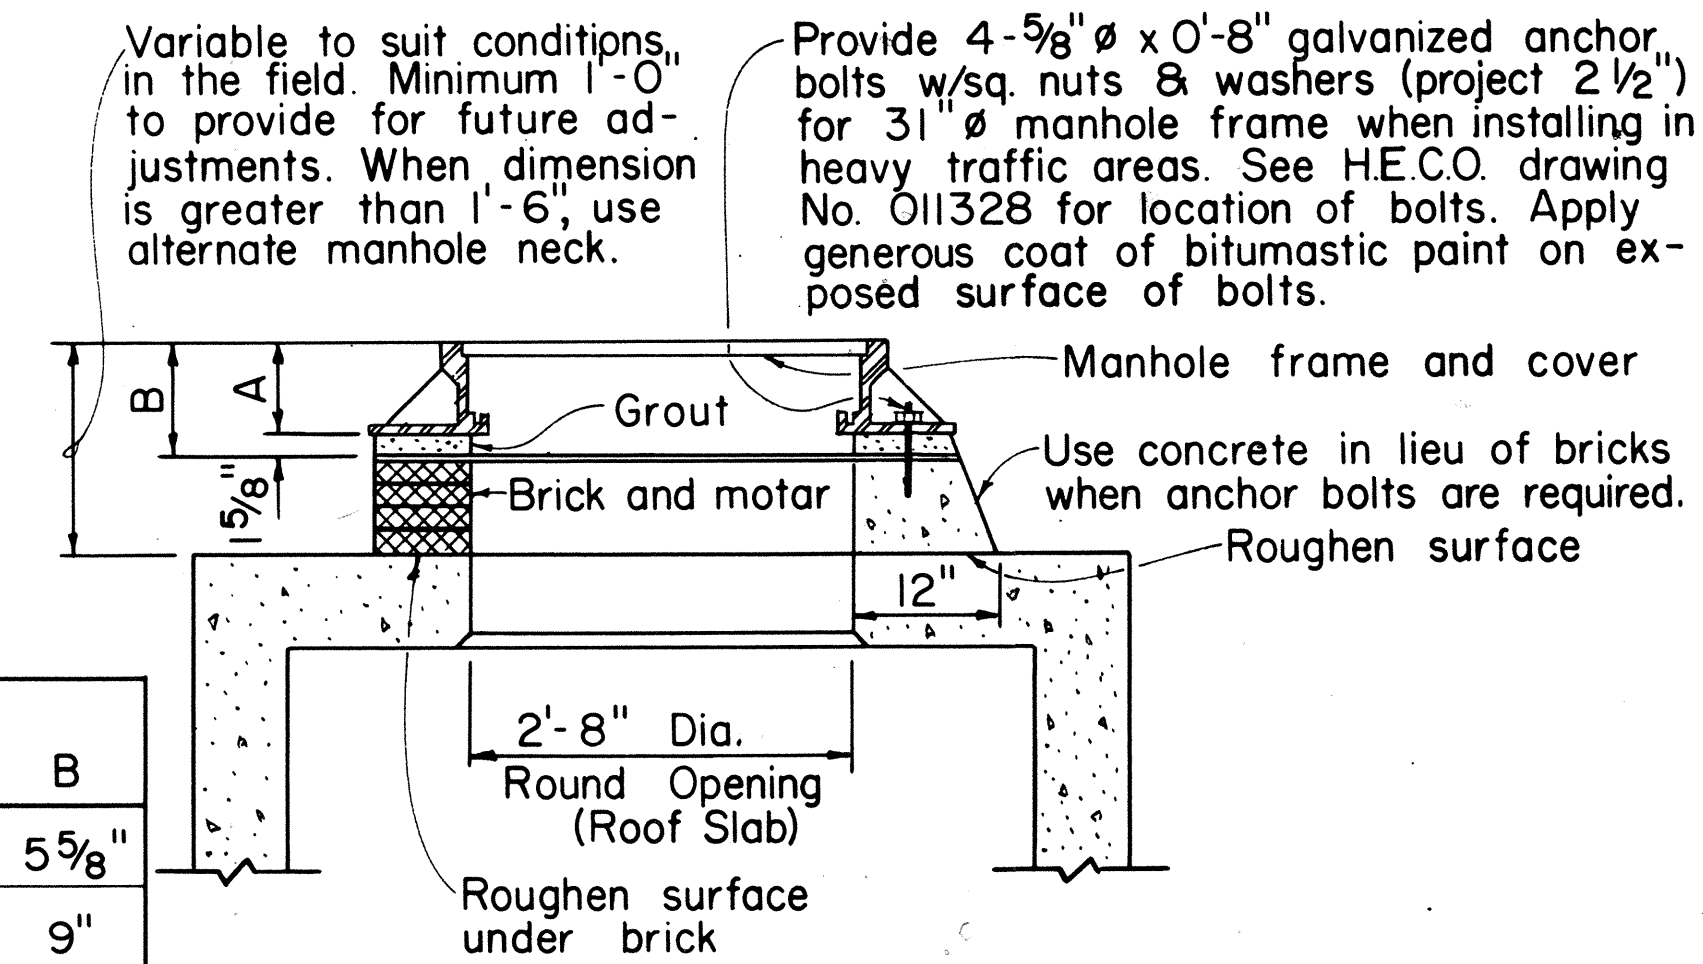





NOTE: See table alternate manhole neck detail for dimension A and B.

APPROVED:



J. Karim
Hawaiian Electric Co., Inc. Date 8/10/77

HECo., Inc. Drawing Number	
16688-A	SHEET NO. 1 OF 2 SHEETS
STATE OF HAWAII DEPARTMENT OF TRANSPORTATION LAND TRANSPORTATION FACILITIES DIVISION	
MISCELLANEOUS DETAILS HANDHOLES & MANHOLES UNDERGROUND STANDARDS (ELECTRIC)	
Scale as noted	
SHEET No. U-9 OF U-23 SHEETS	

FED. ROAD DIST. NO.	STATE	FED. AID PROJ. NO.	FISCAL YEAR	SHEET NO.	TOTAL SHEETS
HAWAII	HAW.	1-HH(131) 17	1977	182	394

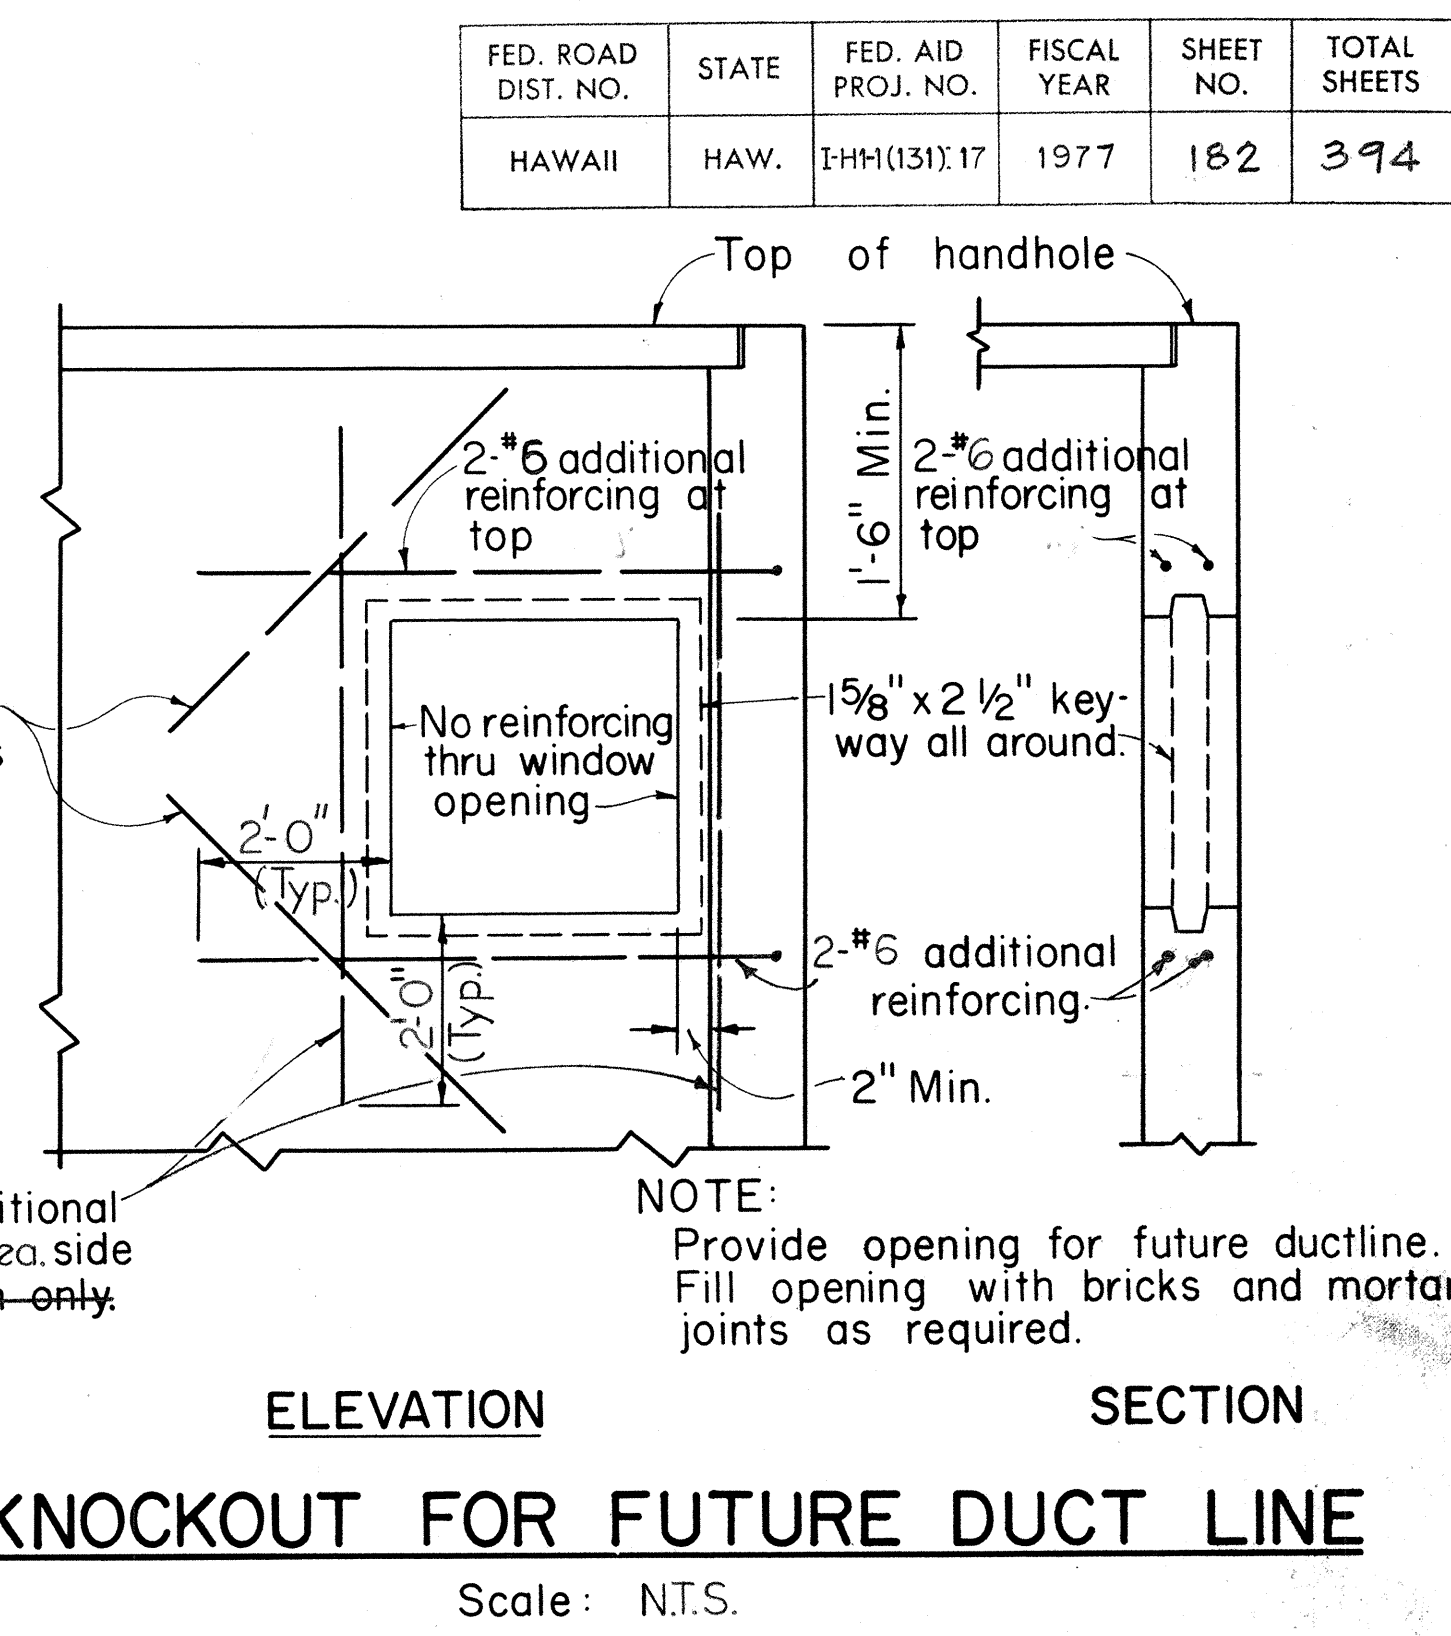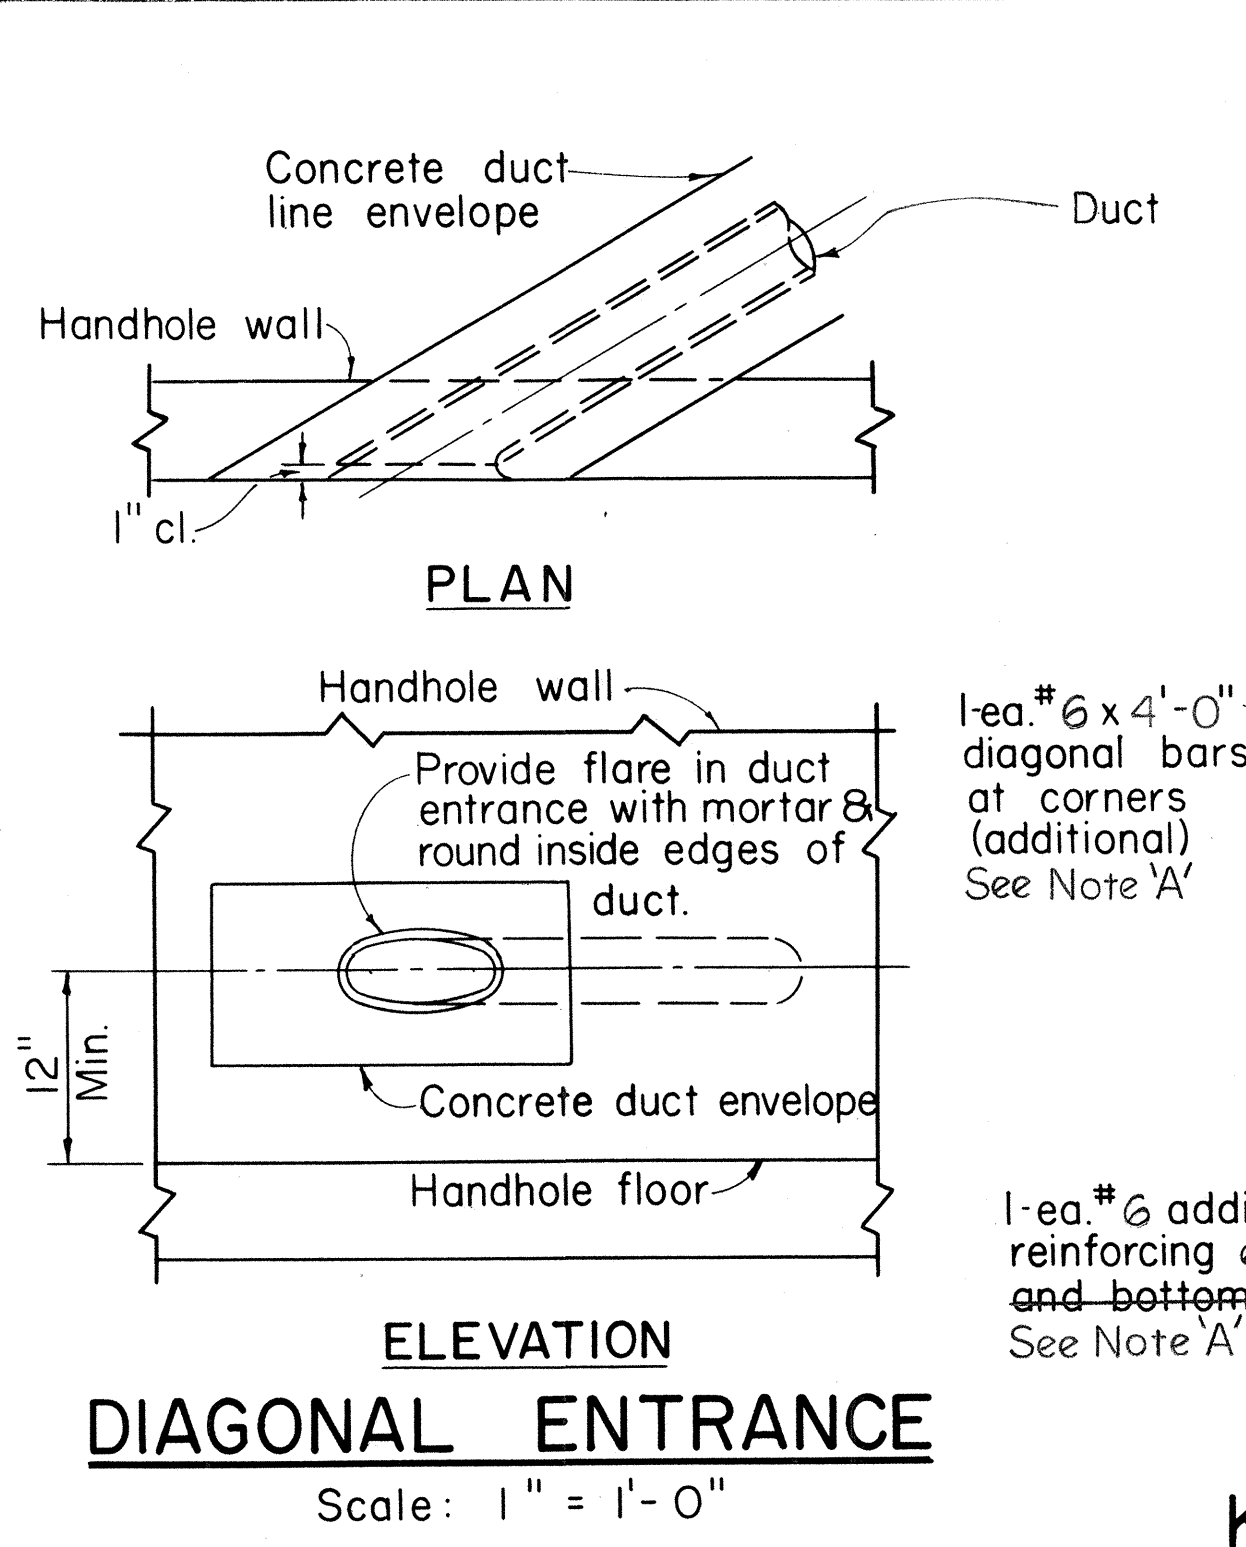
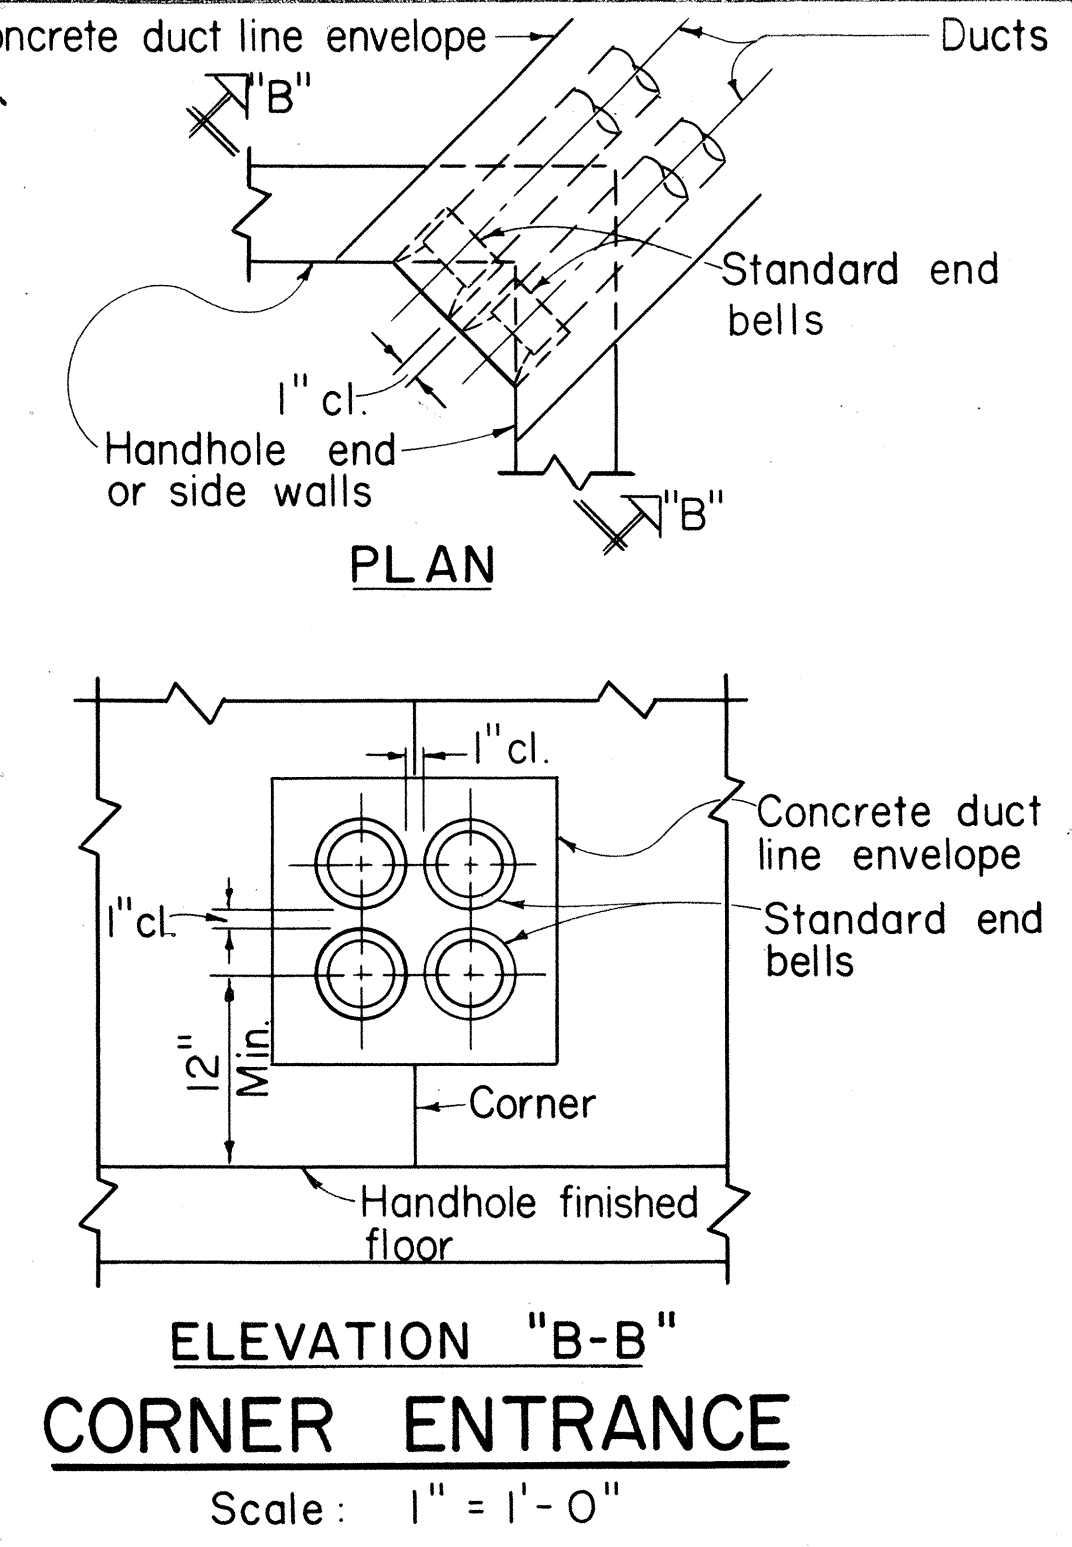
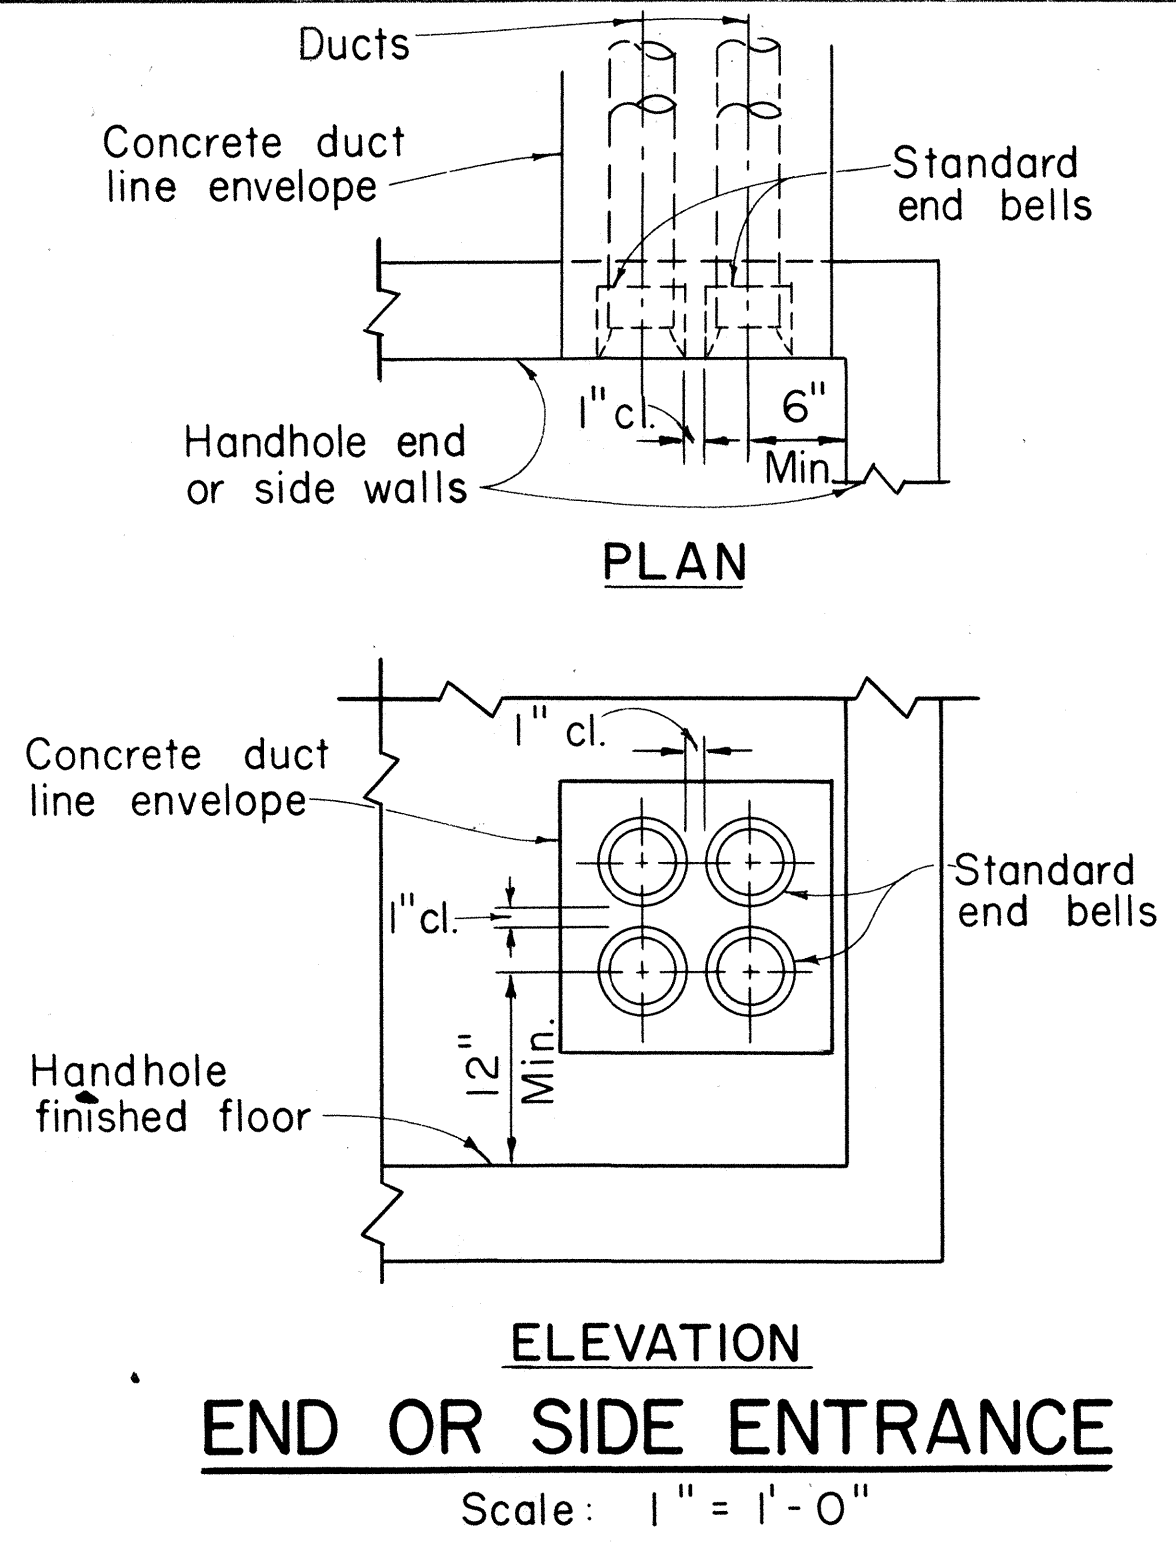


NOTE 'A':
The Reinforcement around opening to be bent where there is insufficient clearance.

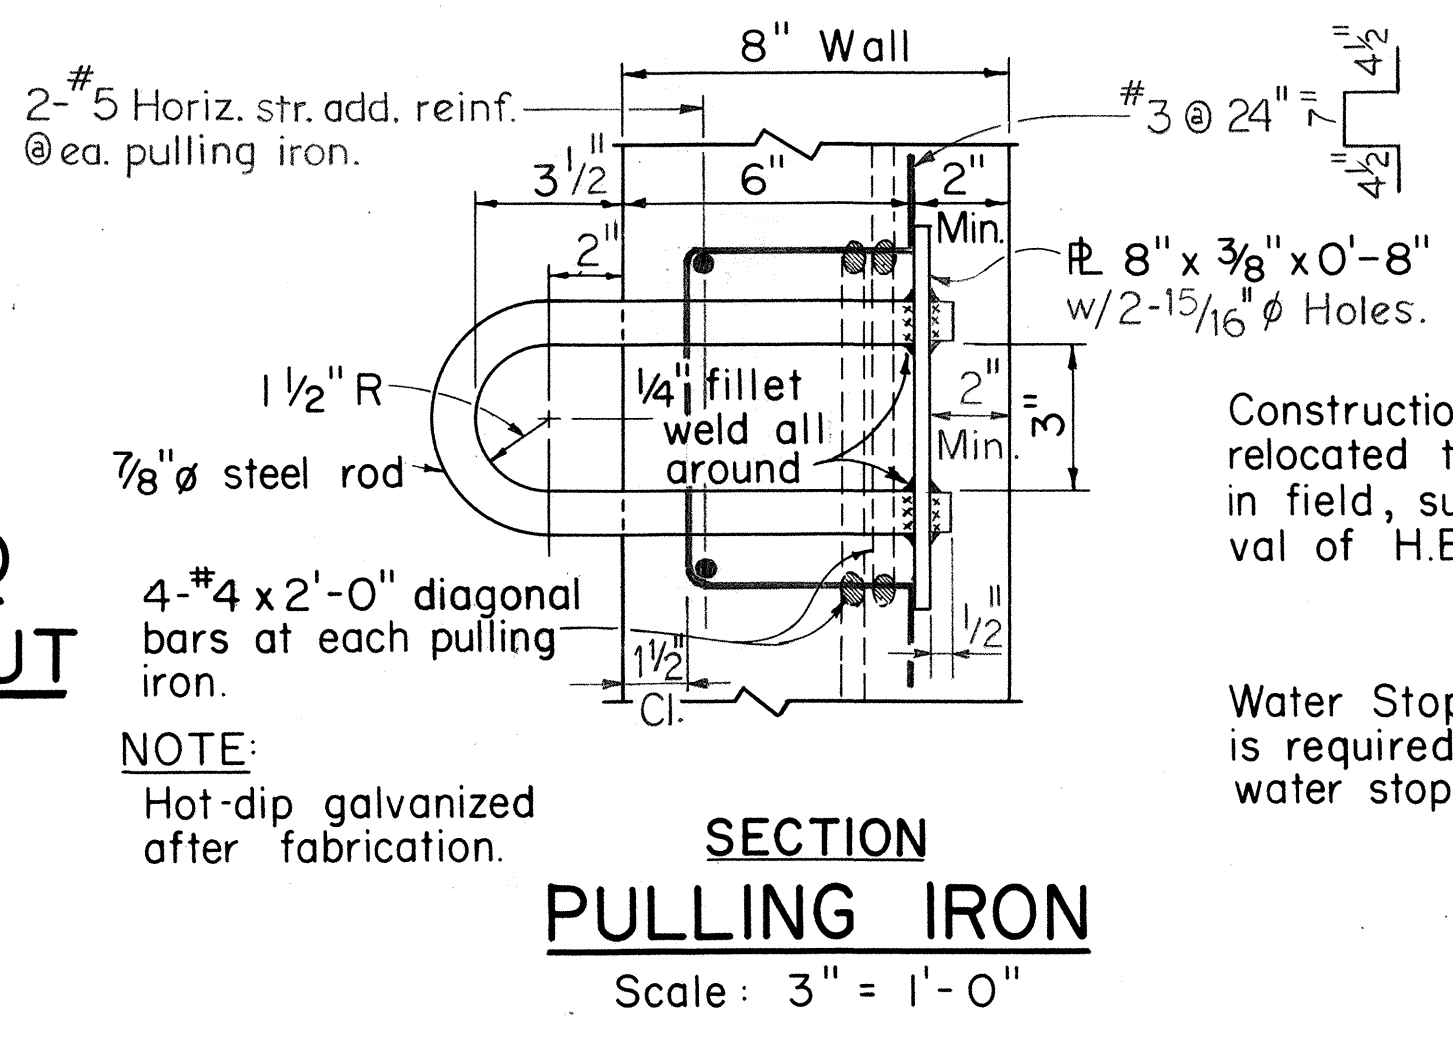
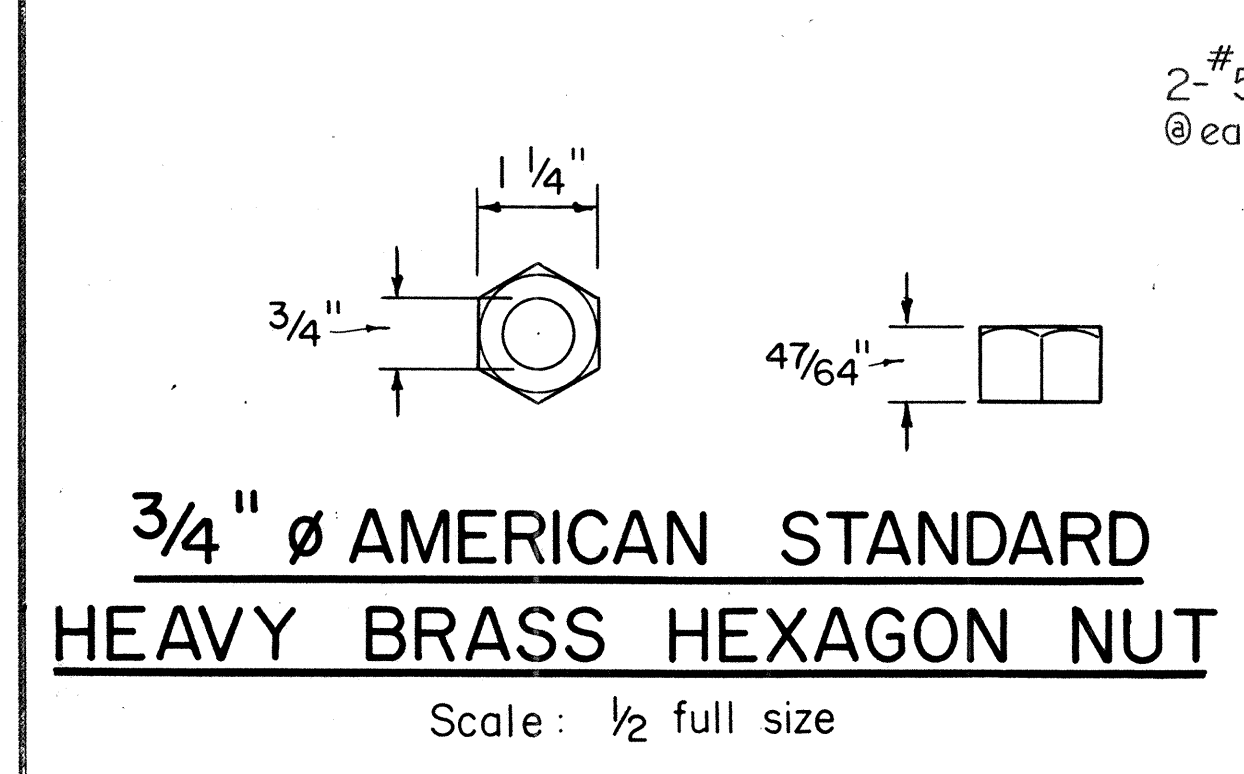


Construction joint may be relocated to suit conditions in field, subject to approval of H.E.Co. Engineer.



Water Stop. If water stop is required, use keylock water stop (KGM 6 x 3/16)

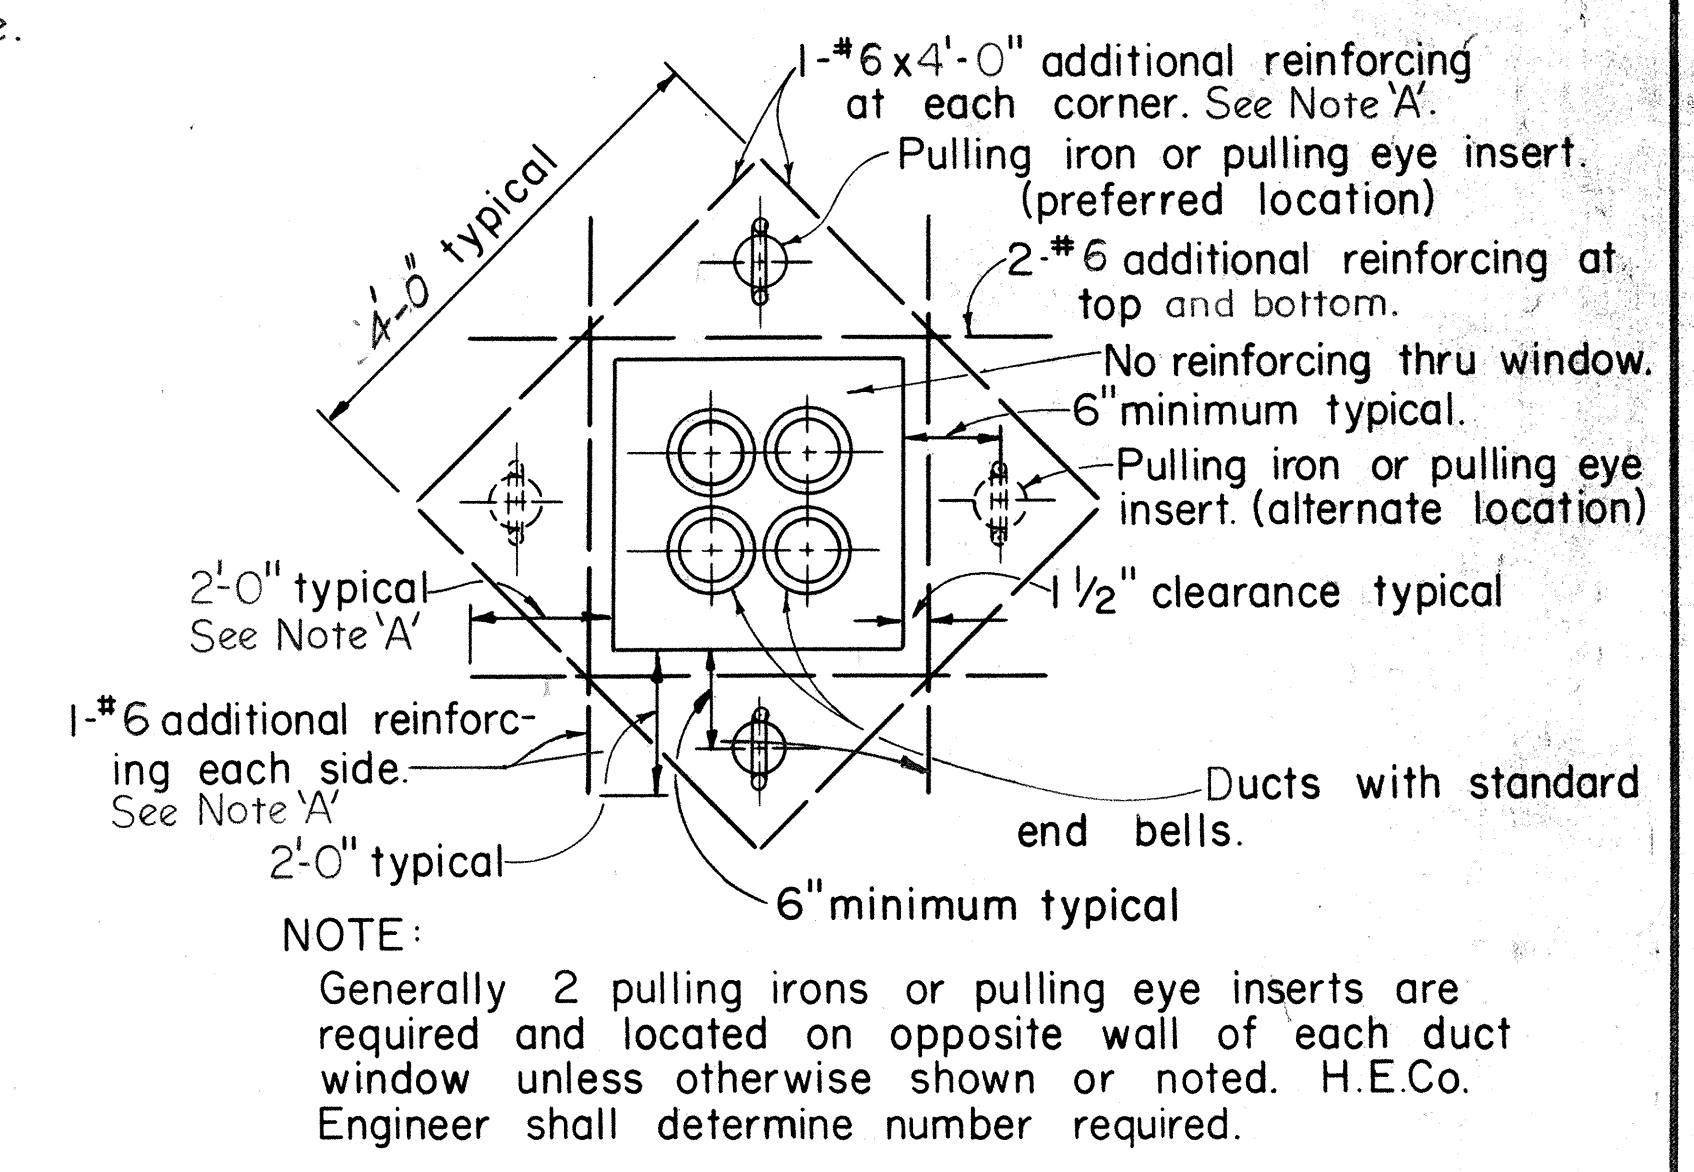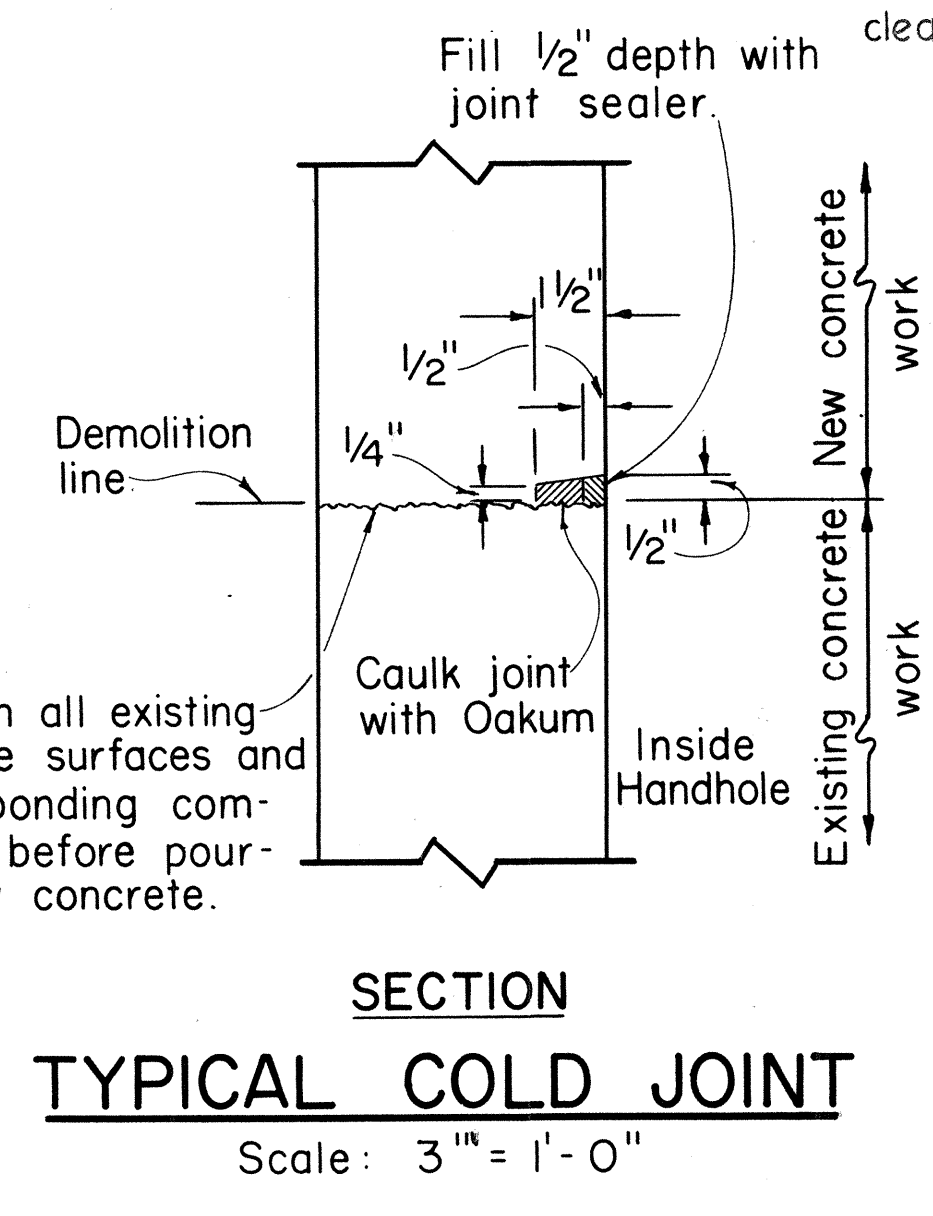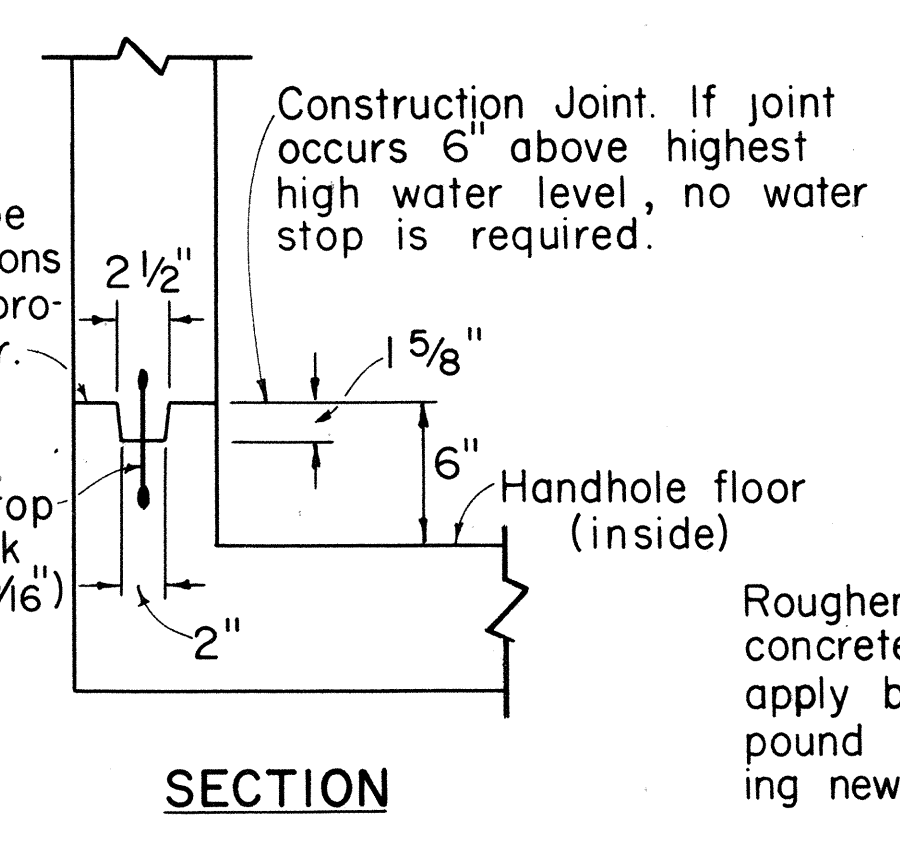

NOTE:
Generally 2 pulling irons or pulling eye inserts are required and located on opposite wall of each duct window unless otherwise shown or noted. H.E.Co. Engineer shall determine number required.

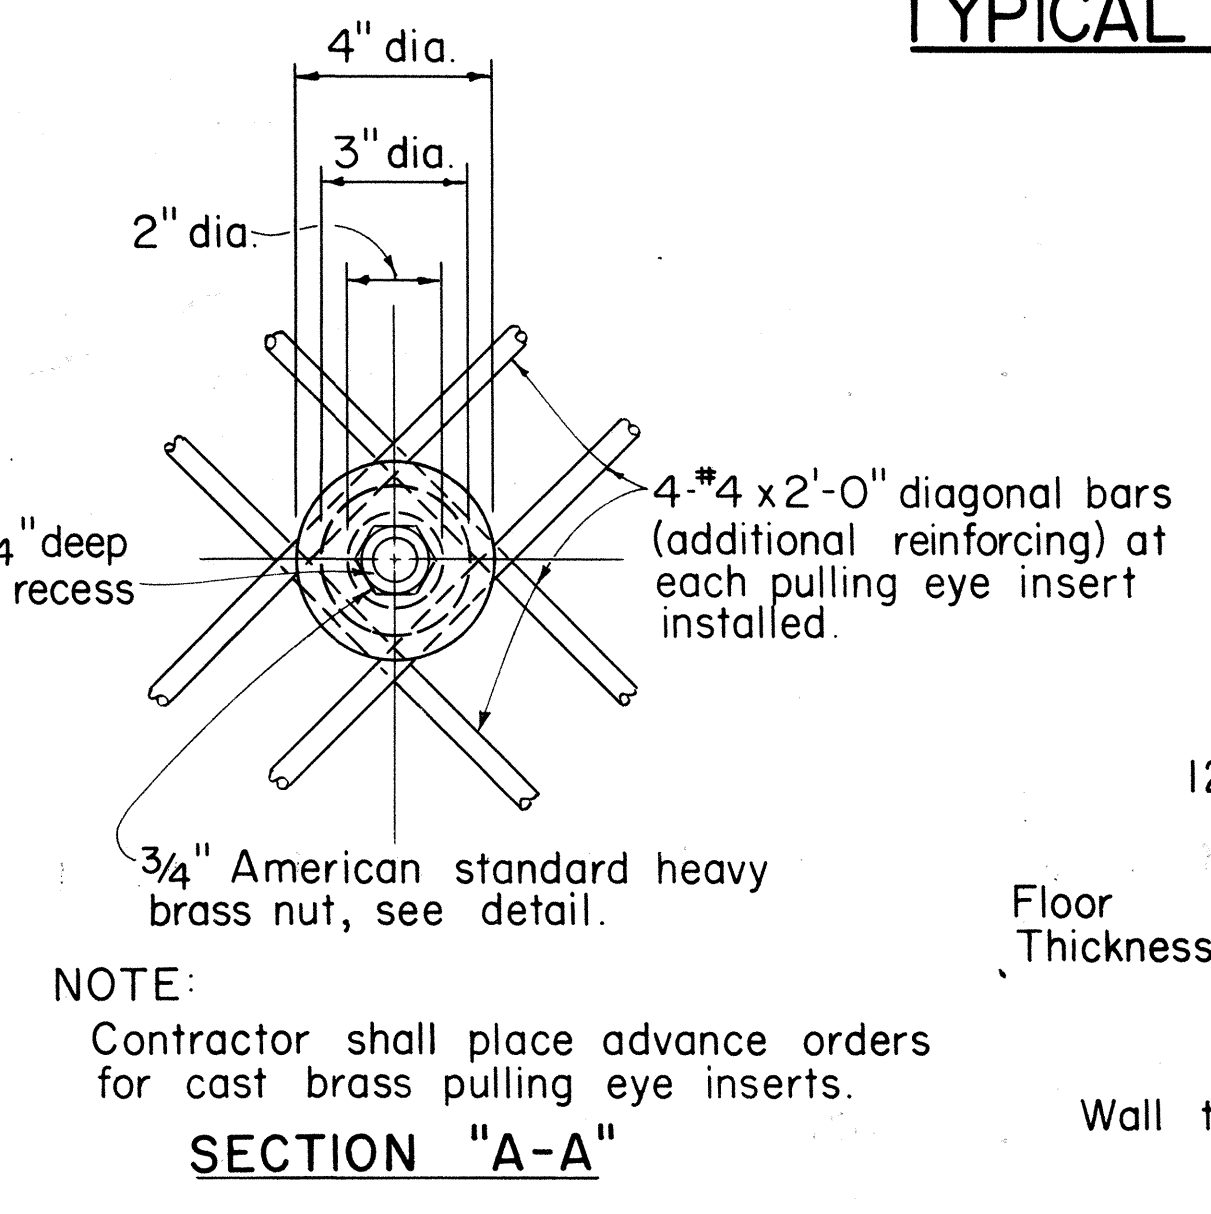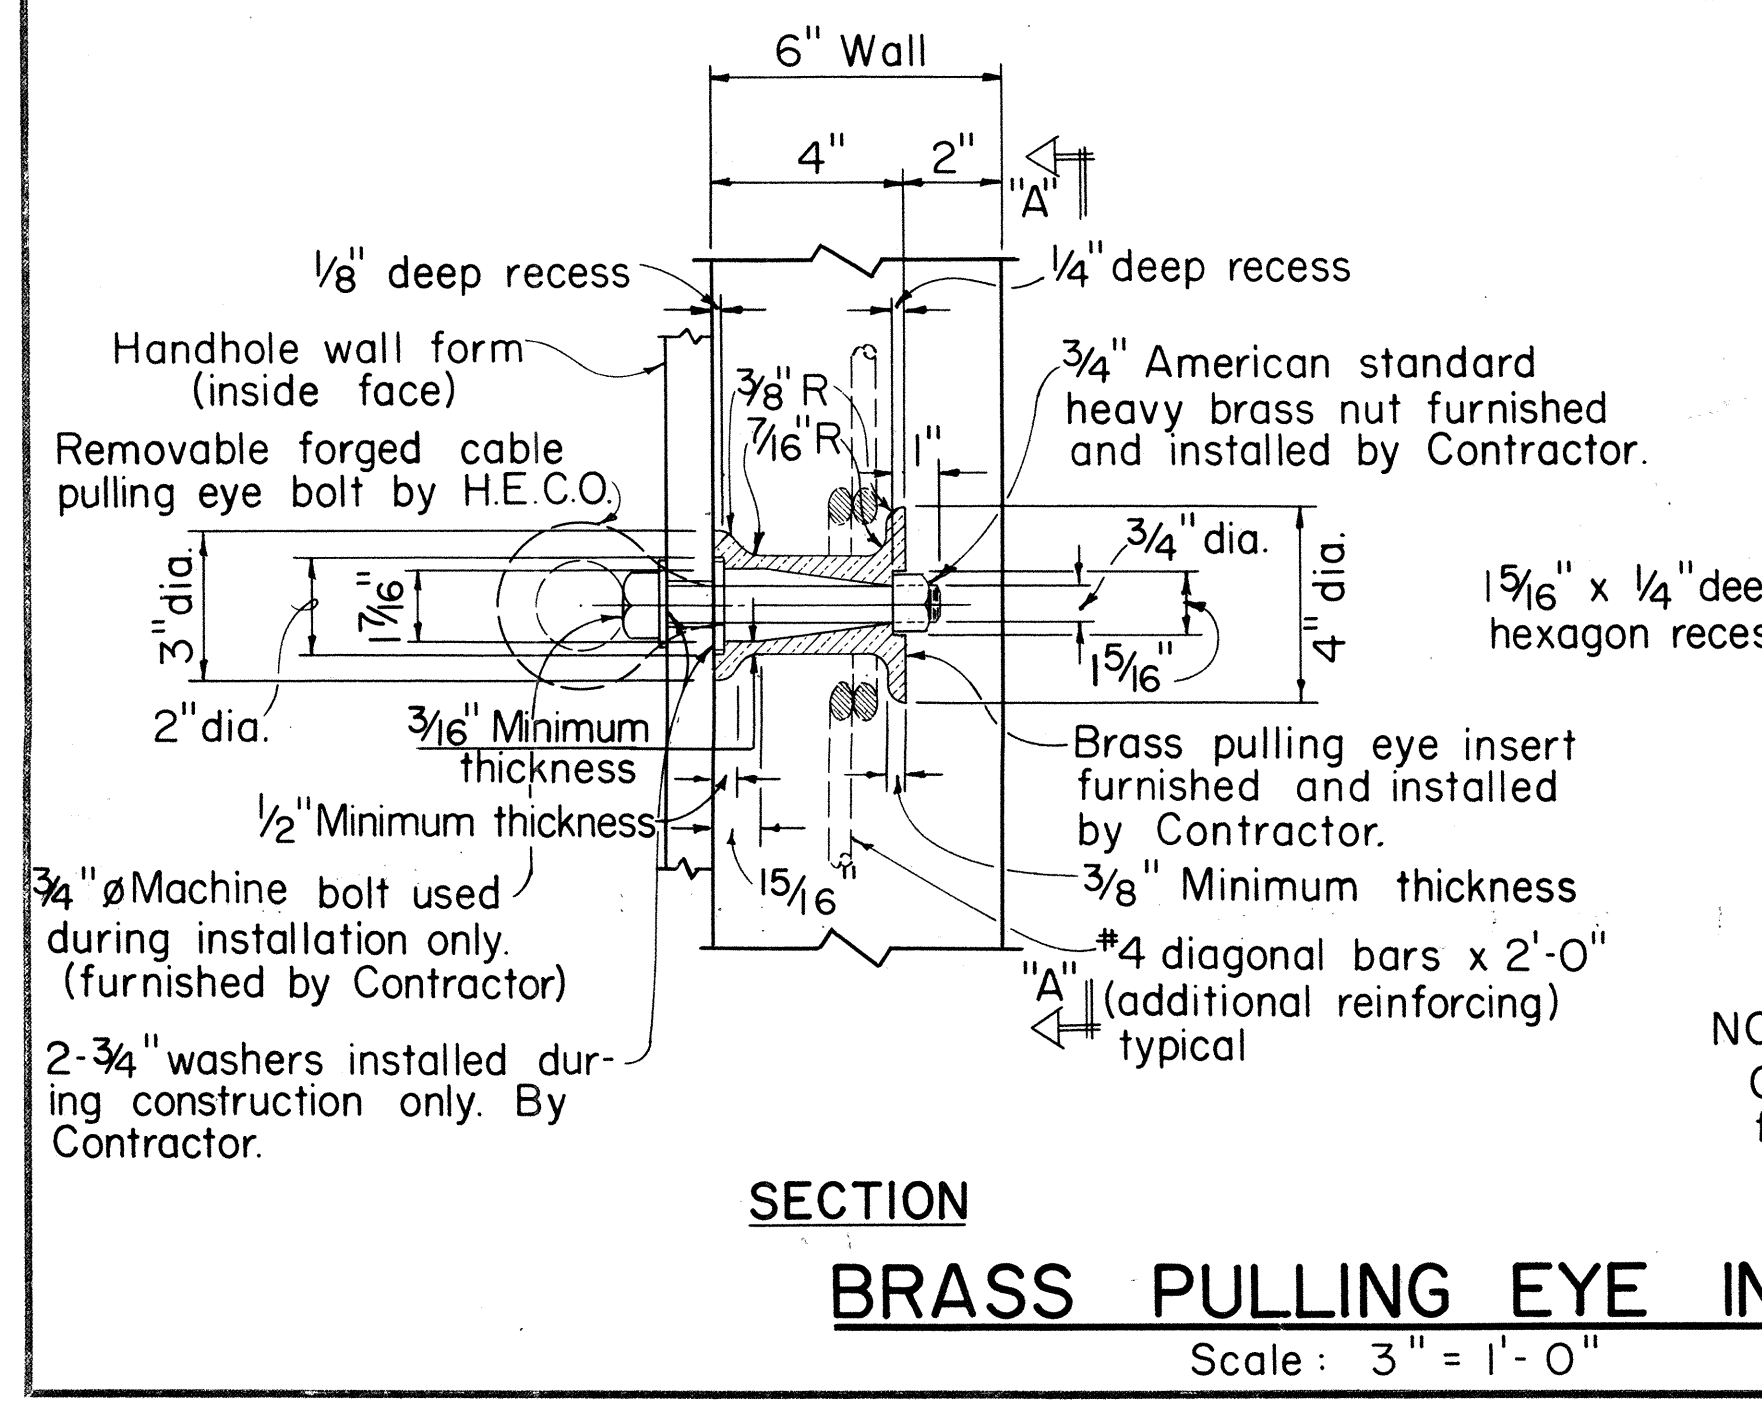

NOTE:
Contractor shall place advance orders for cast brass pulling eye inserts.

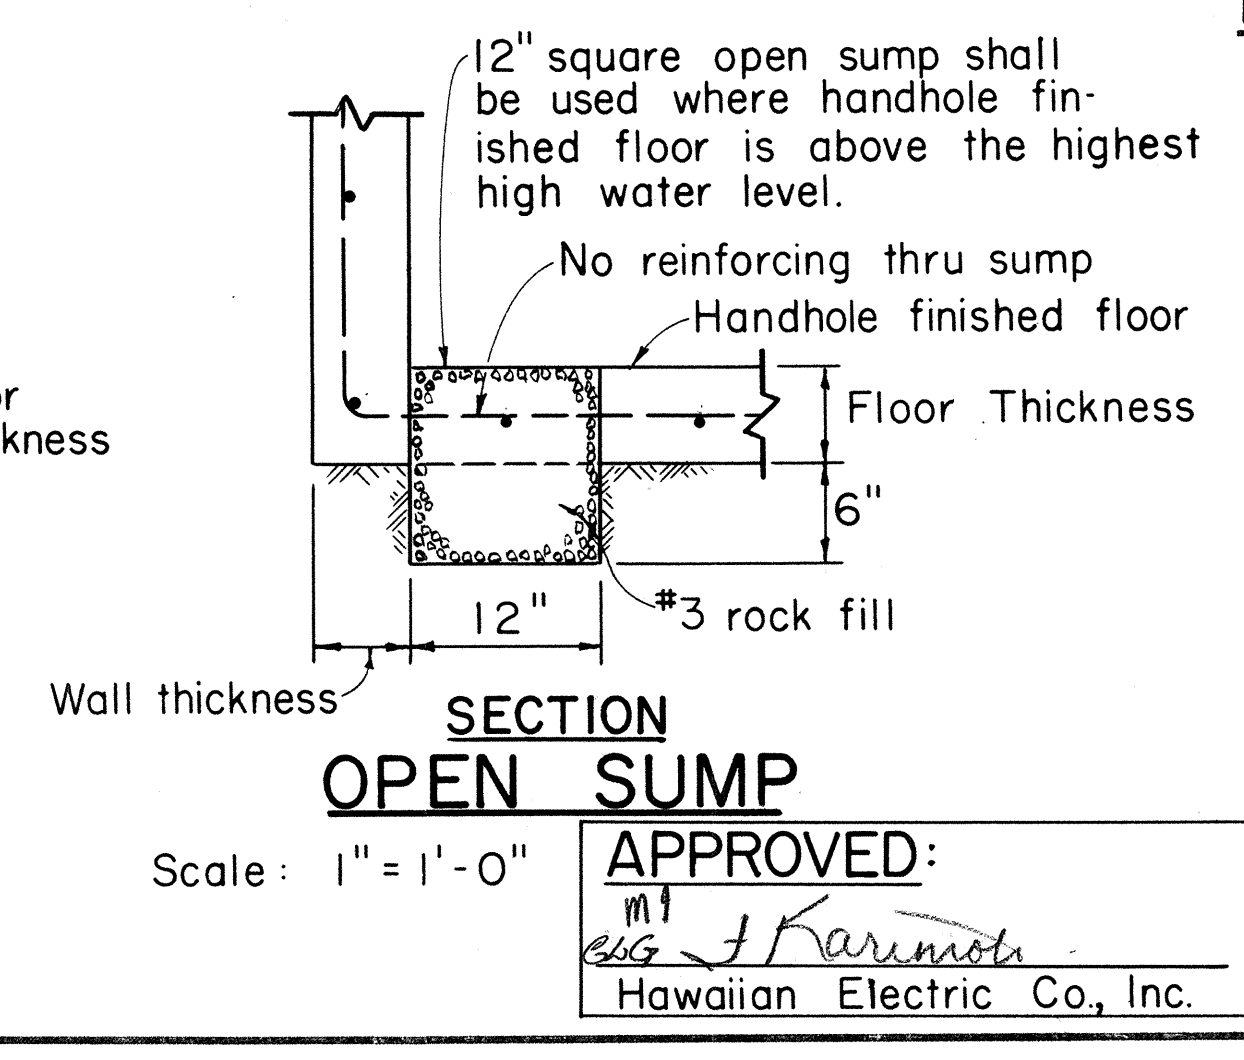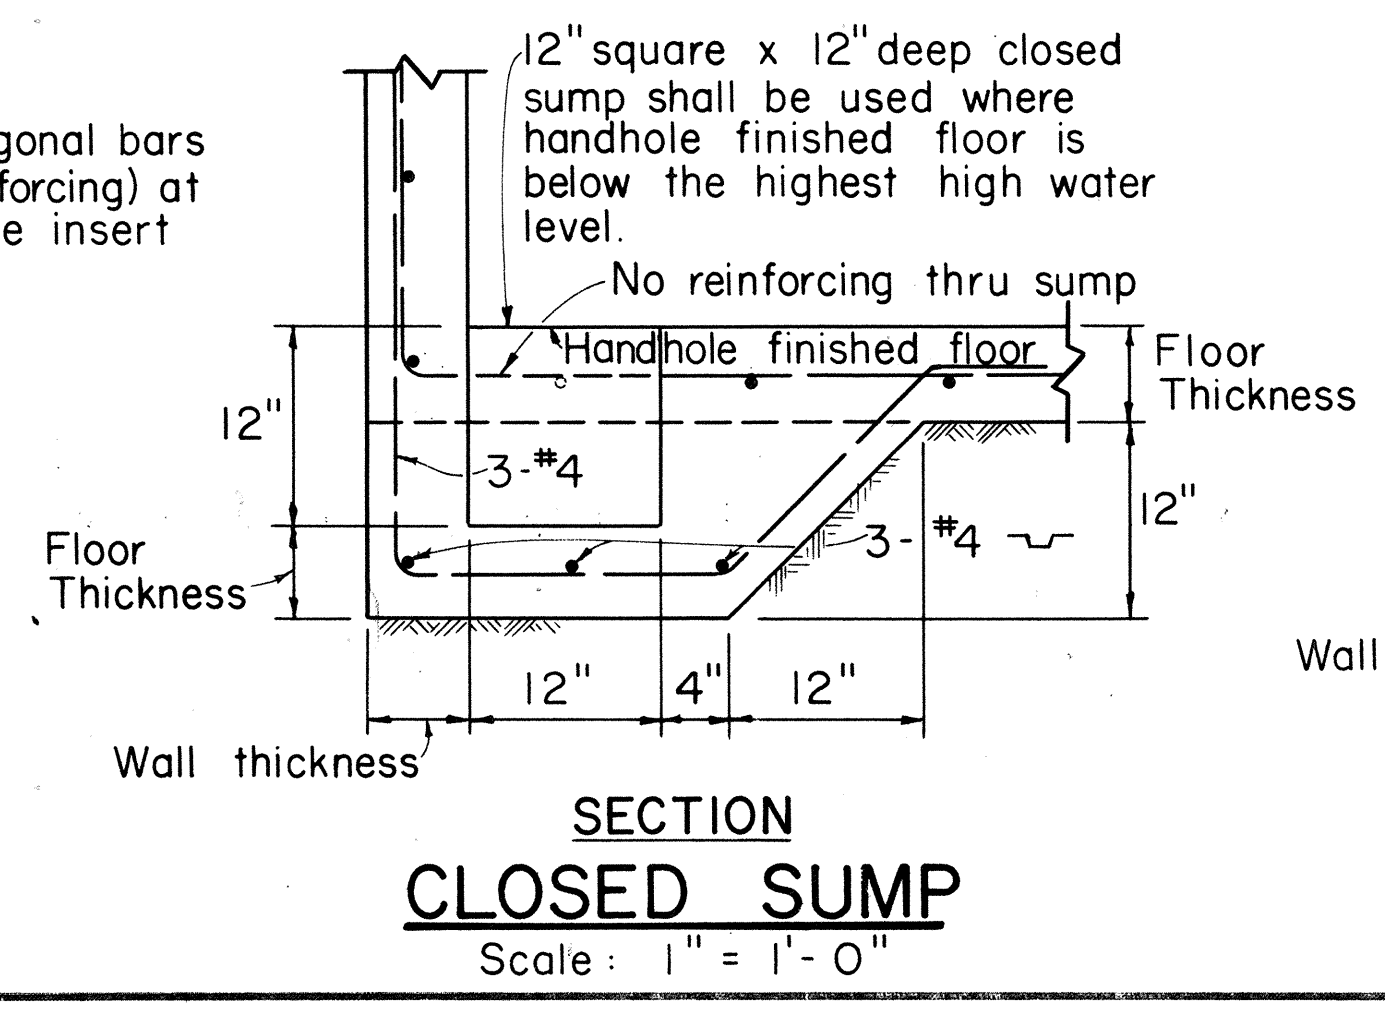

APPROVED:
Hawaiian Electric Co., Inc. Date 8/10/77




HECo., Inc. Drawing Number
16688-A SHEET NO. 2 OF 2 SHEETS

STATE OF HAWAII
DEPARTMENT OF TRANSPORTATION
LAND TRANSPORTATION FACILITIES DIVISION

**MISCELLANEOUS DETAILS
HANDHOLES & MANHOLES
UNDERGROUND STANDARDS
(ELECTRIC)**



Scale as noted
SHEET No. U-10 OF U-23 SHEETS

FED. ROAD DIST. NO.	STATE	FED. AID PROJ. NO.	FISCAL YEAR	SHEET NO.	TOTAL SHEETS
HAWAII	HAW.	1-HH-1(30)-17	1977	184	394

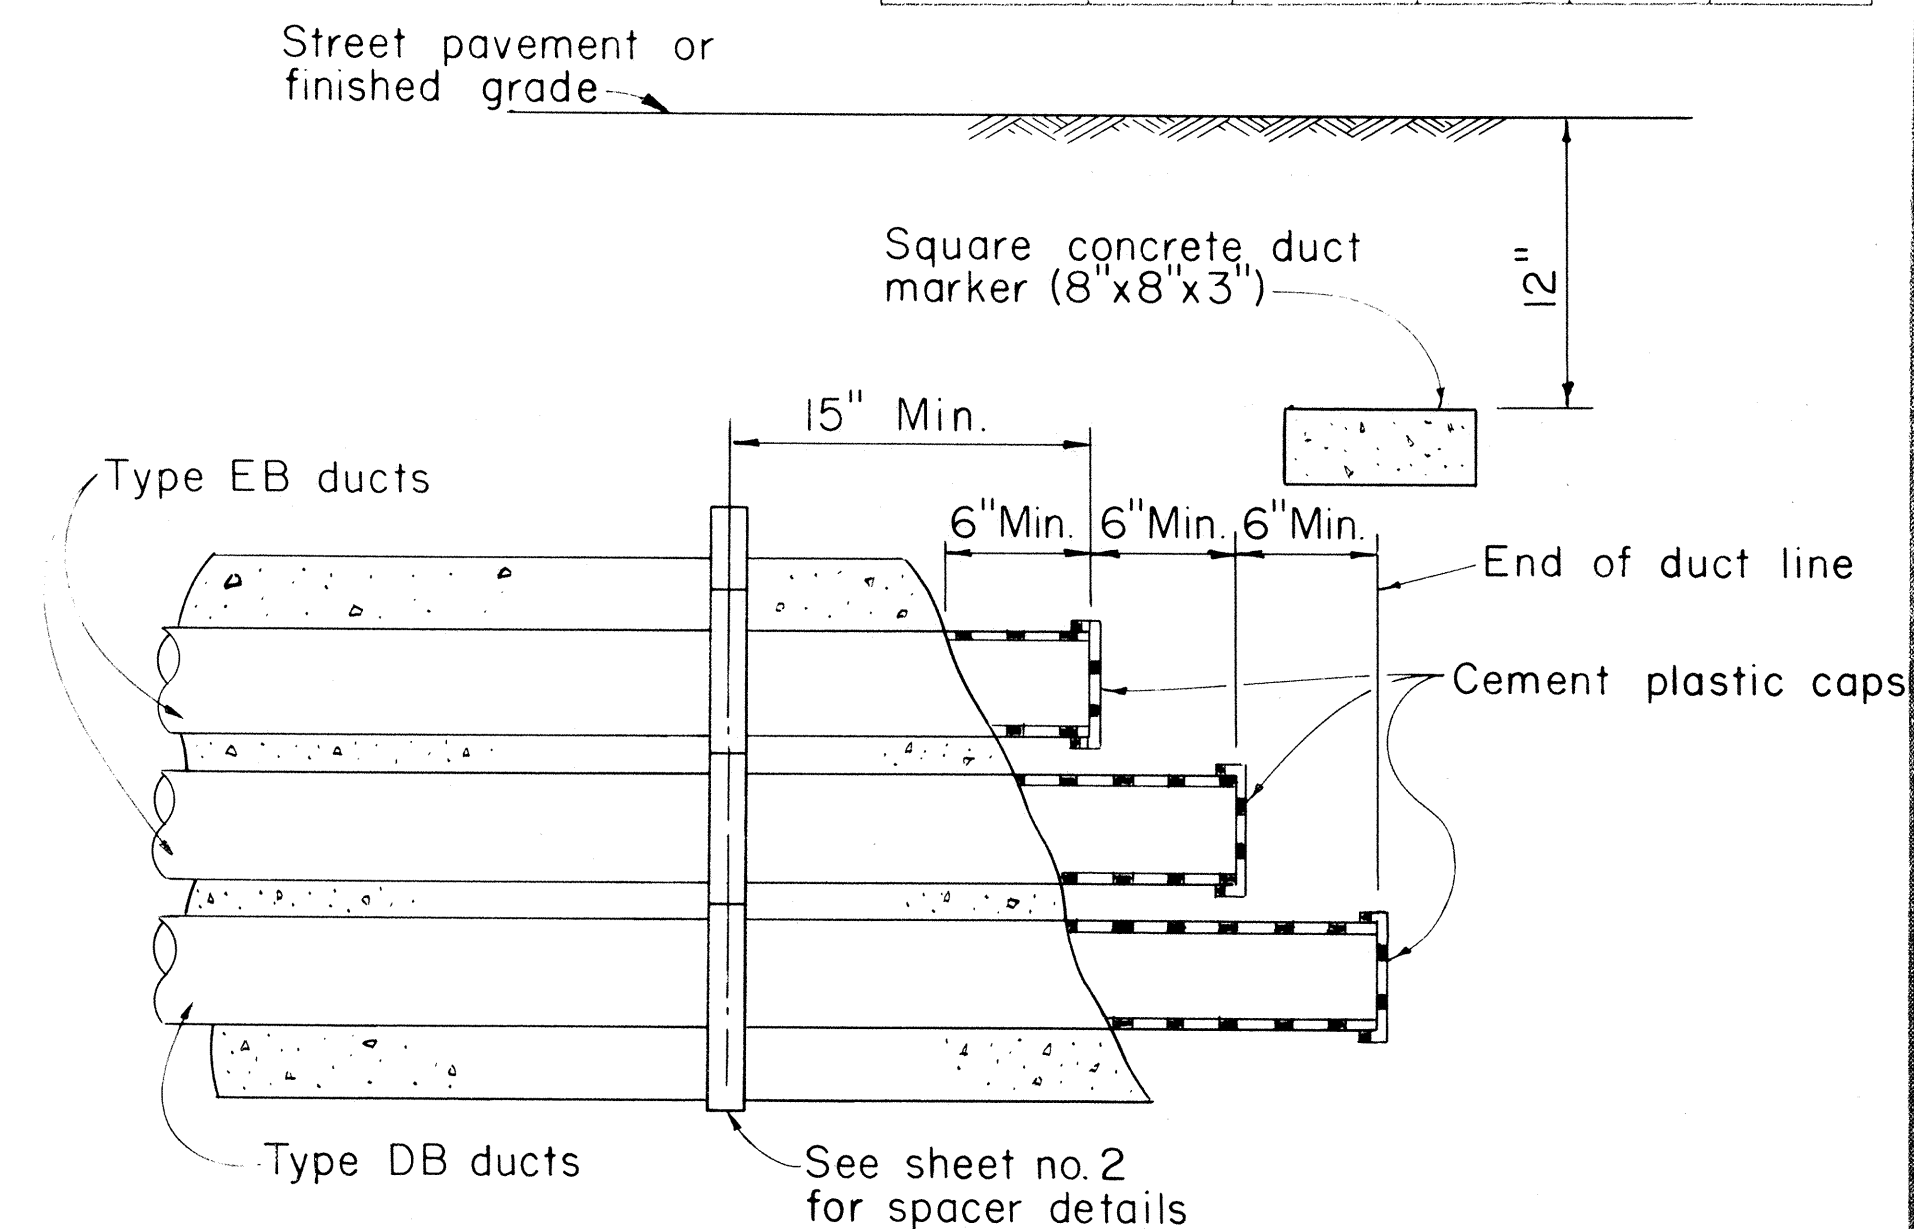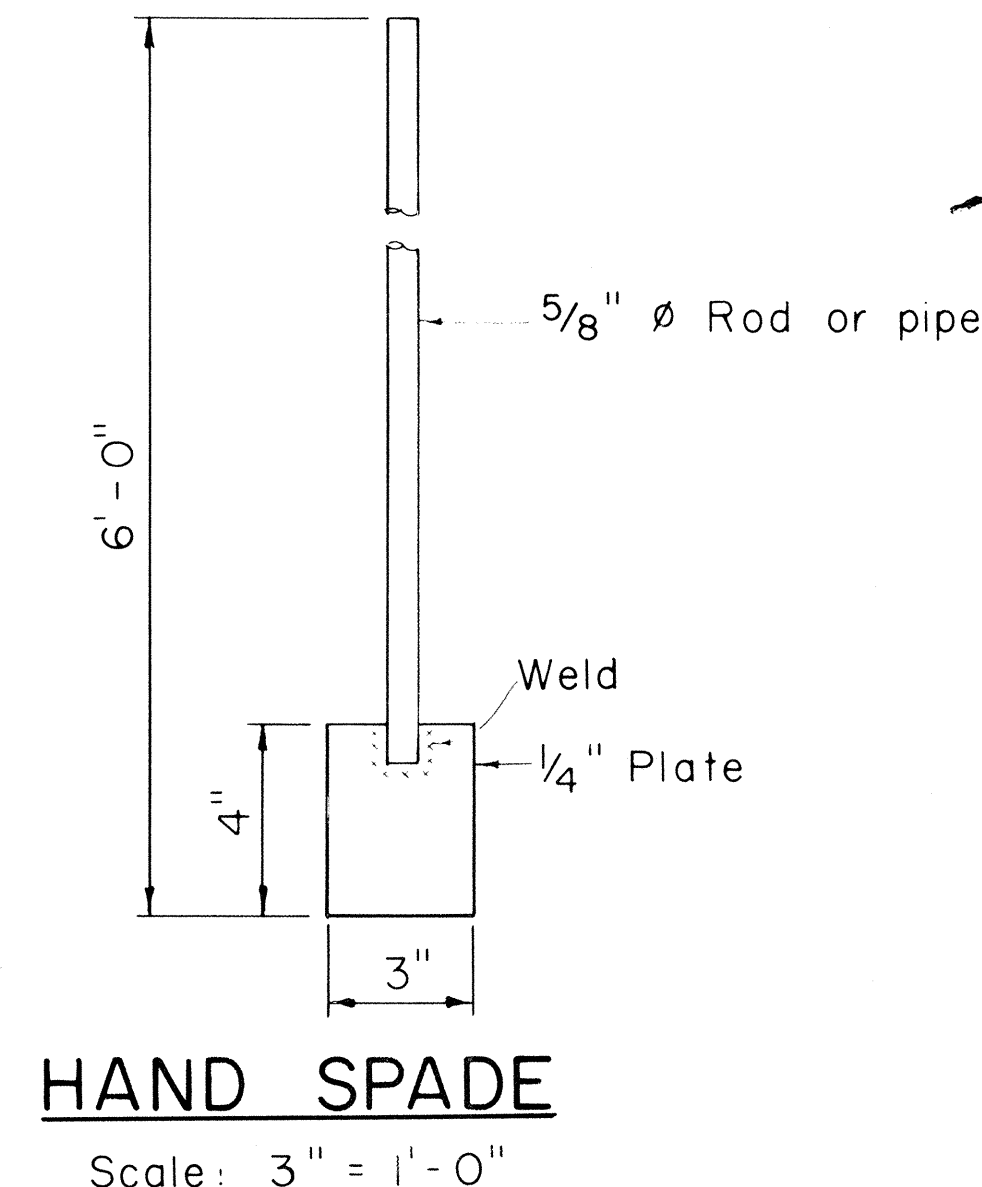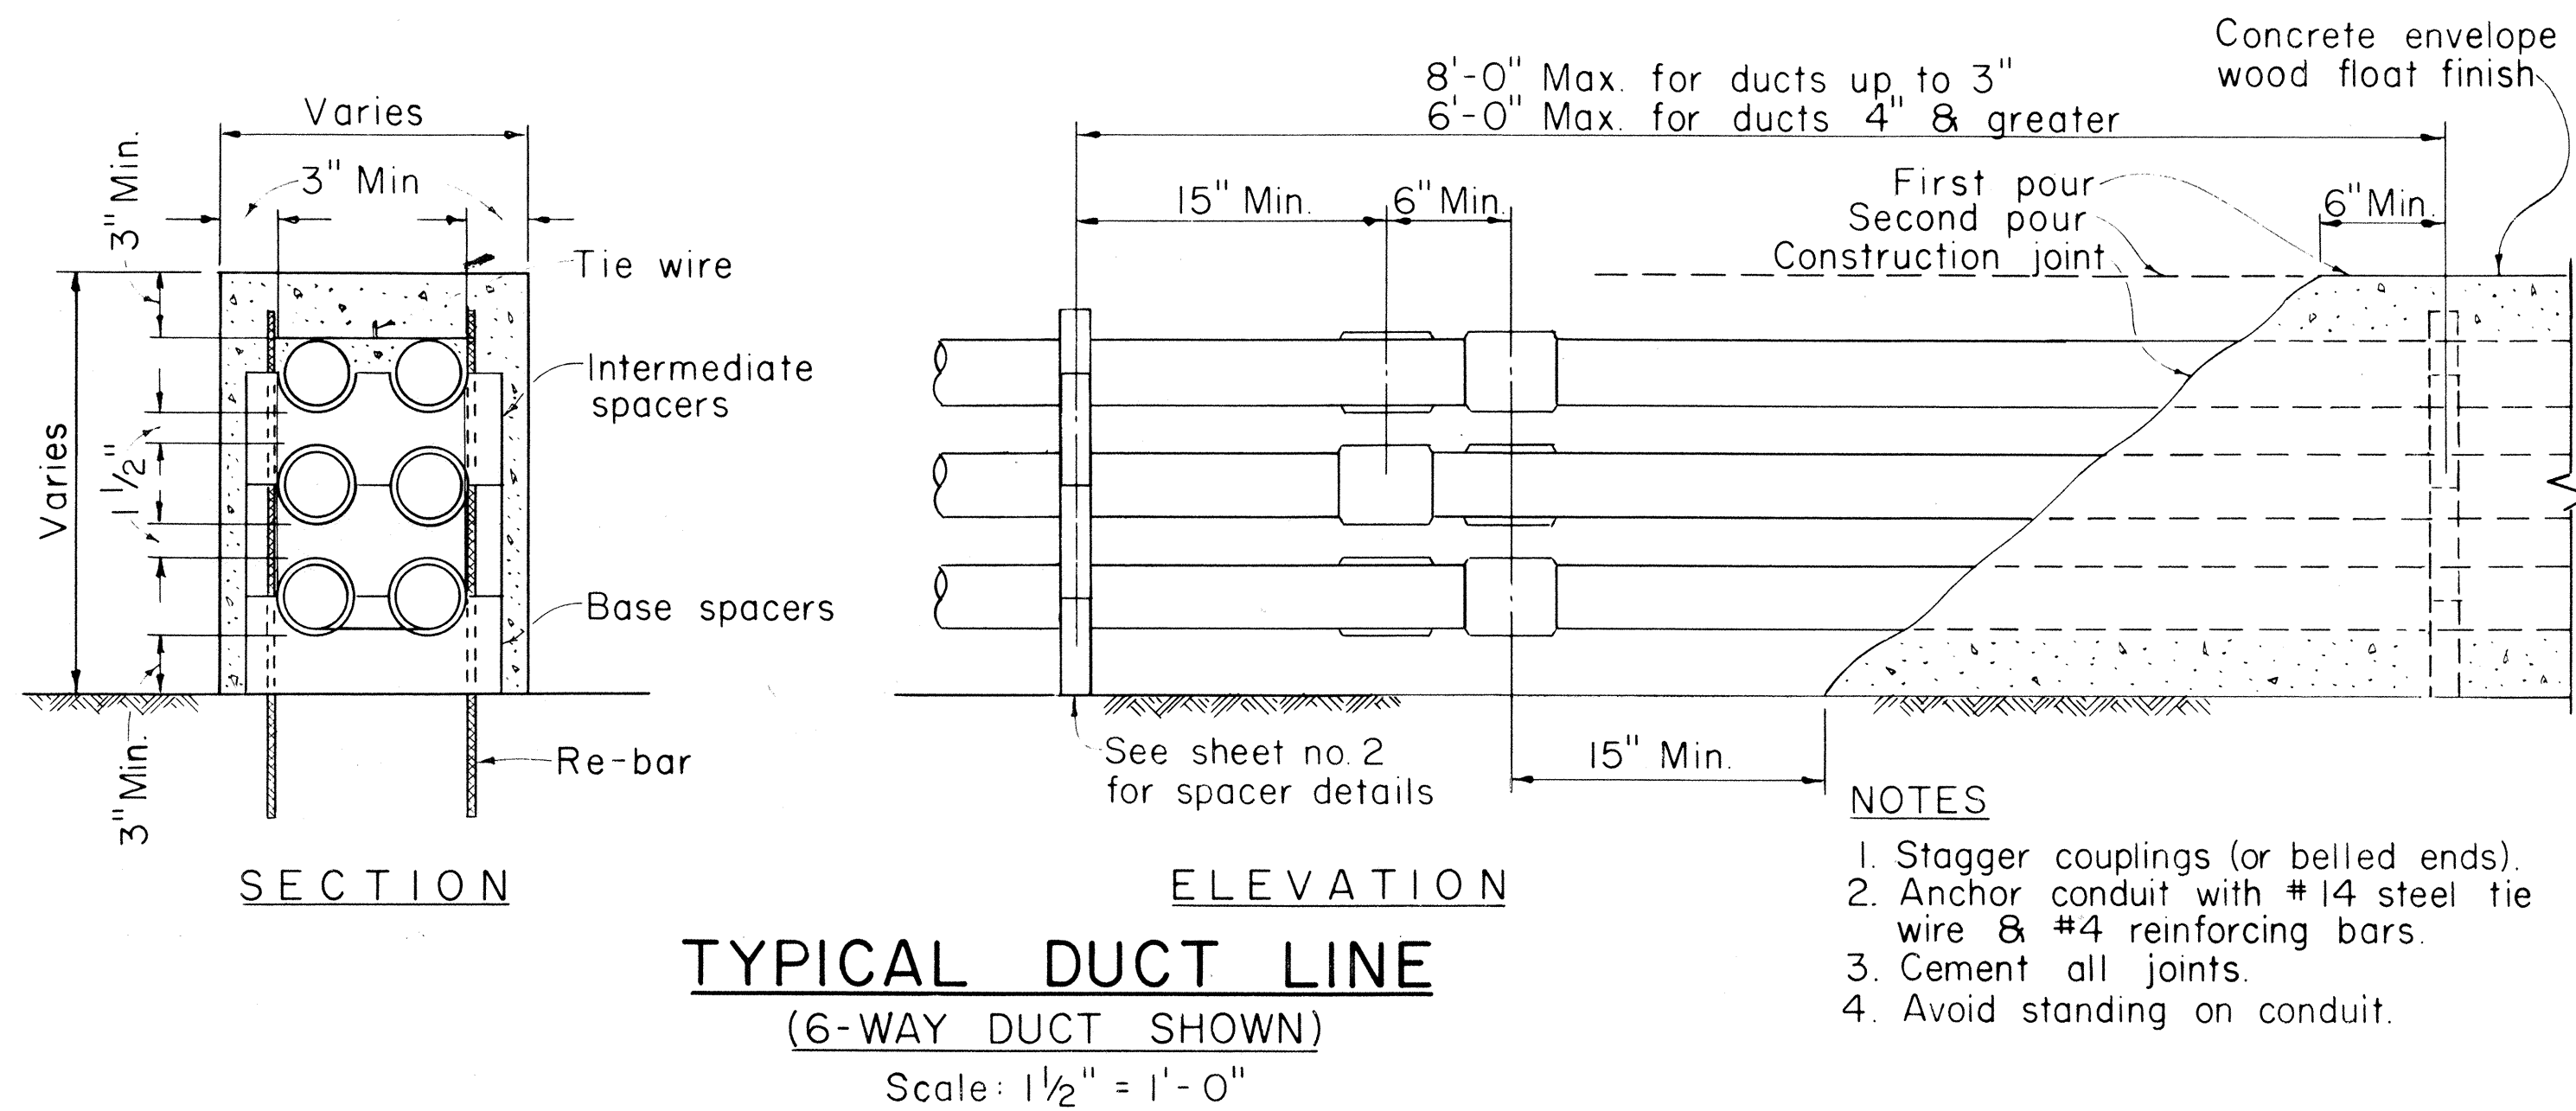

TYPICAL STUB OUT DETAIL
(6-WAY DUCT SHOWN)
Scale: 1 1/2" = 1'-0"

- NOTE:
1. Maintain 1 1/2" minimum spacing between conduit, 3" minimum concrete envelope around top, bottom & sides.
 2. Dimensions are minimum dimensions.
 3. The bottom row in an encased duct bank of three or more layers shall be Type DB ducts. The remaining ducts shall be Type EB.
 4. Refer to G0-10 or specified project drawings for depth requirements.

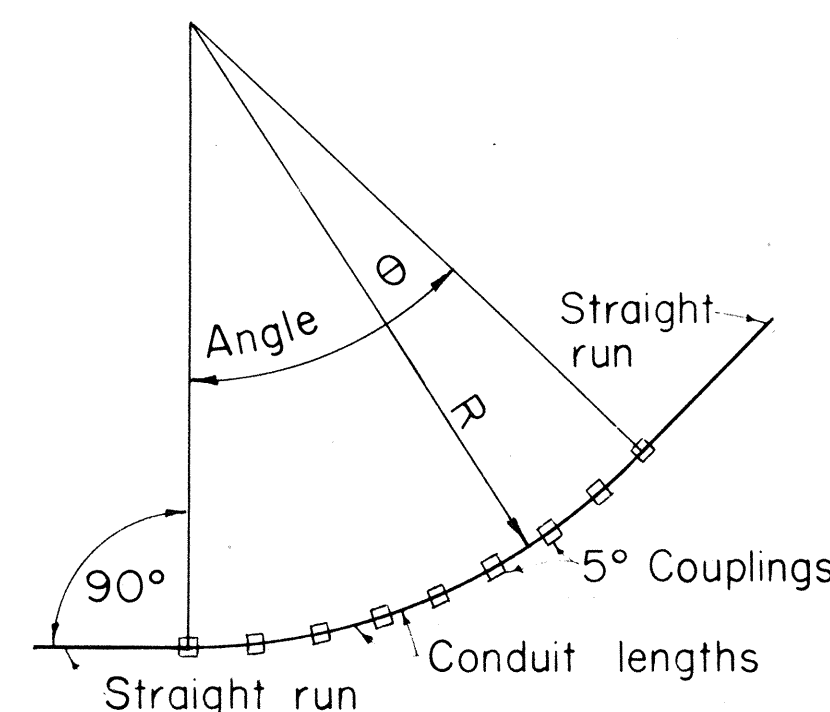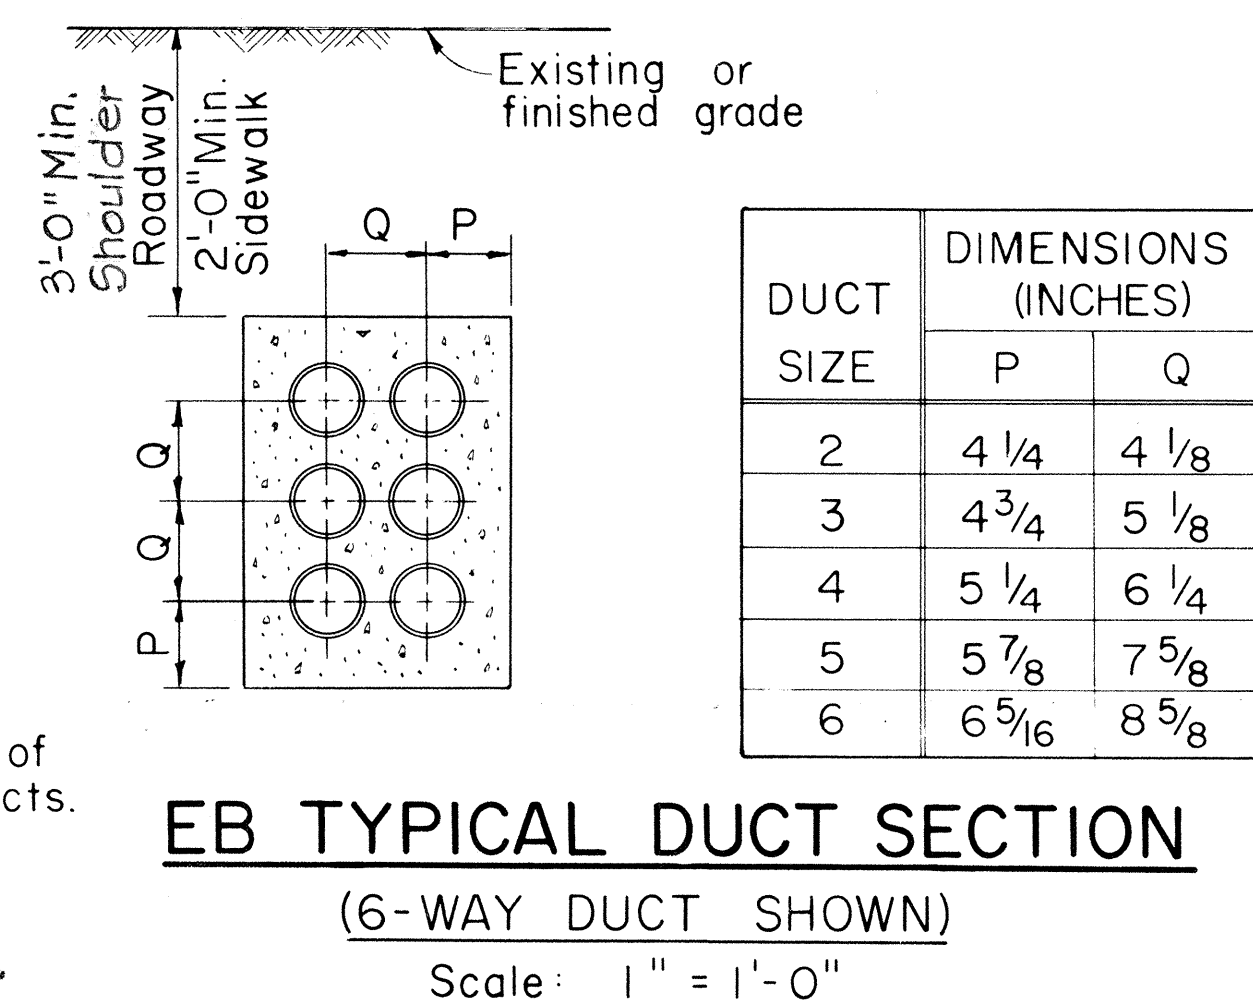

EXAMPLE:

Radius of bend (R) = 60'
Angle of bend (θ) = 45°

From Table A, the nearest value to 60' radius is 57'-6". Length of conduit = 5'.

From Table B, for 45° angle.
Number of couplings required = 9
Number of conduit lengths required = 8

METHOD OF FORMING CURVES:

There are 4 methods of forming curves with plastic conduit.

1. "Cold" bending: Limit trench formed radius sweeps to 25' minimum radius.
2. "Heat" bending: Do not heat bend conduit.
3. 5° angle couplings may be used as shown.
4. Factory made elbows and sweeps may be used only when specified by Engineer.

APPLICATION OF 5° COUPLING FOR LONG RADIUS BENDS

REFERENCE SPECIFICATION

CS 7202	General Conditions
CS 7001	Construction of U.G. Facilities
CS 7003	Construction of Electrical Facilities

APPROVED:

J. Karimata
Hawaiian Electric Co., Inc. Date 8/14/77


GENERAL NOTES

A. APPROVED CONDUIT MATERIALS

1. Encased Burial (EB) Conduit
 - a) Asbestos Cement, Type I ----- M7005
 - b) ABS (Acrylonitrile-Butadiene-Styrene) Plastic Conduit, Type EB ----- M7001
 - c) PVC (Polyvinyl Chloride) Plastic Conduit, Type EB ----- M7001
 - d) PVC Plastic Conduit, Schedule 40 ----- 116
2. Direct Burial (DB) Conduit
 - a) ABS Plastic Conduit, Type DB ----- M7001
 - b) PVC Plastic Conduit ----- M7001
 - c) PVC Plastic Conduit, Schedule 40 ----- 116

B. This drawing provides details for installing Plastic Ducts (ABS & PVC) only. Refer to drawing 30-1030 & 30-1033 for installing Asbestos Cement Ducts Encased Burial.

HECO PURCHASE SPECIFICATION NO.

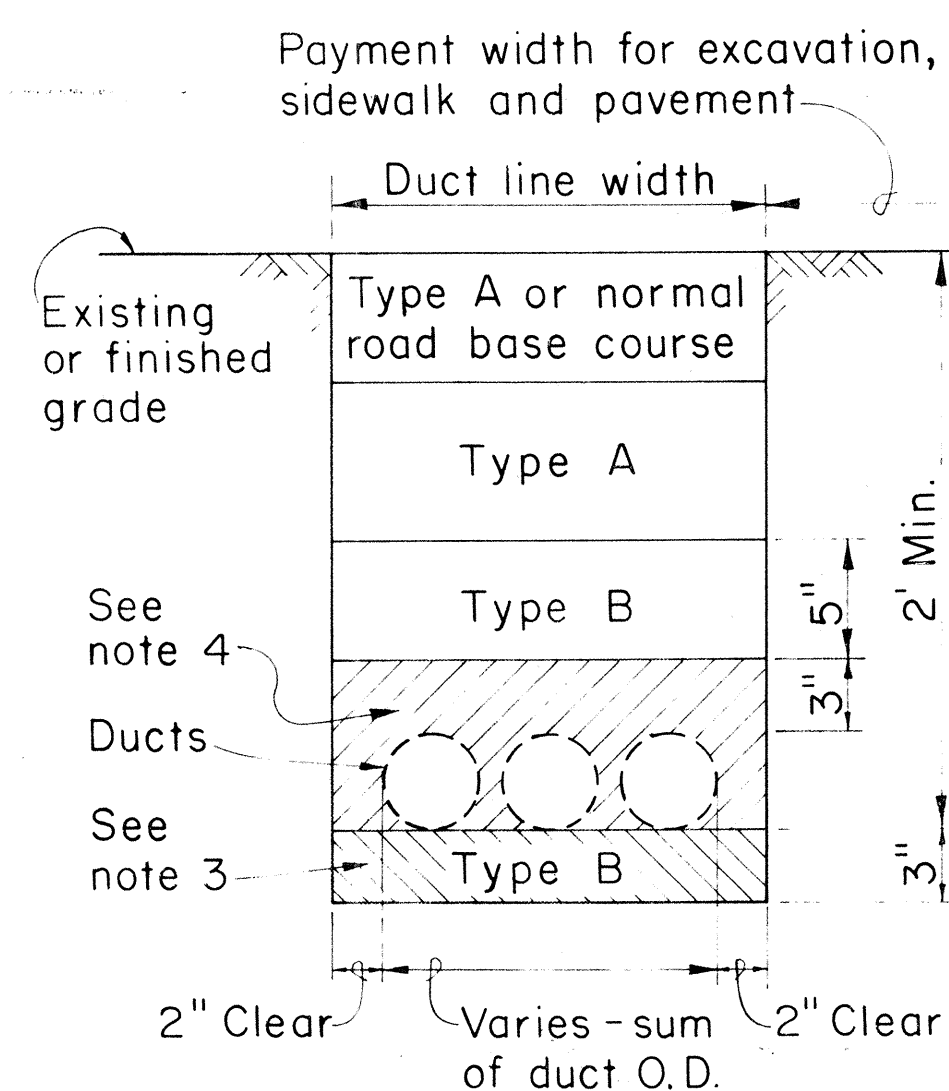


D.B. EXCAVATION & BACKFILL DETAILS (TYPICAL)


Scale 1 1/2" = 1'-0"

HECO, Inc. Drawing Number	
30-1035-A SHEET No. 1 OF 2 SHEETS	
STATE OF HAWAII DEPARTMENT OF TRANSPORTATION LAND TRANSPORTATION FACILITIES DIVISION	
STANDARD DETAILS	
PLASTIC DUCTS INSTALLATION DETAILS UNDERGROUND STRUCTURES (ELECTRIC)	
Scale as noted	
SHEET No. 4-12 OF 23 SHEETS	


FED. ROAD DIST. NO.	STATE	FED. AID PROJ. NO.	FISCAL YEAR	SHEET NO.	TOTAL SHEETS
HAWAII	HAW.	1-HI-1(13)	1977	185	395

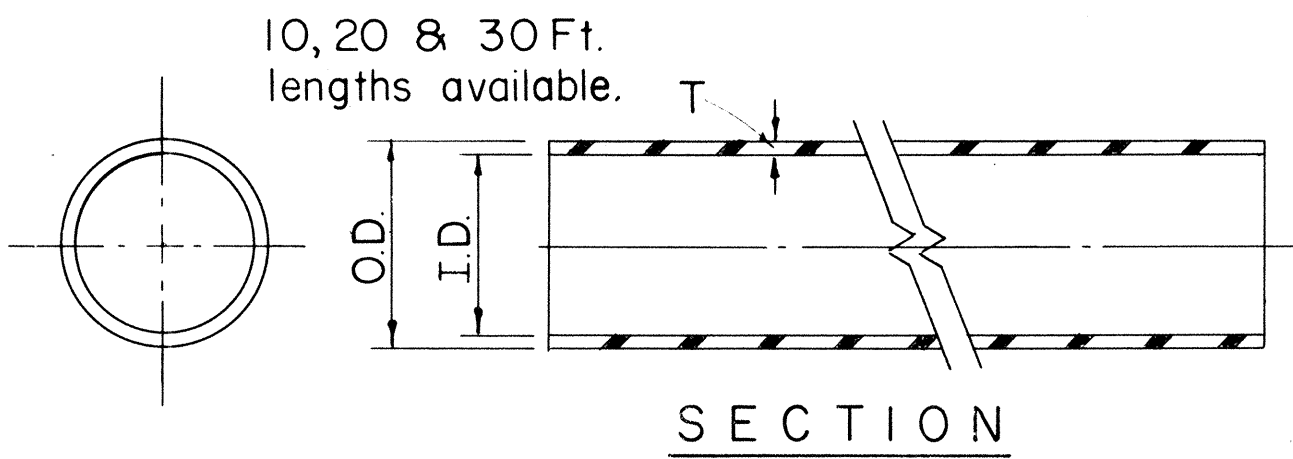


CONDUIT

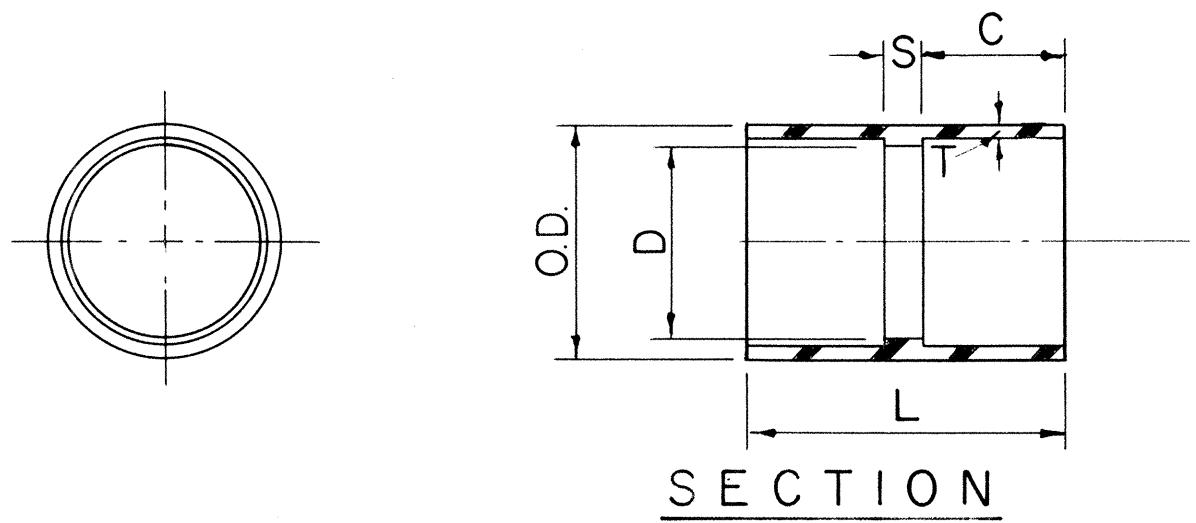


C O U P L I N G (ASTM D-2750)

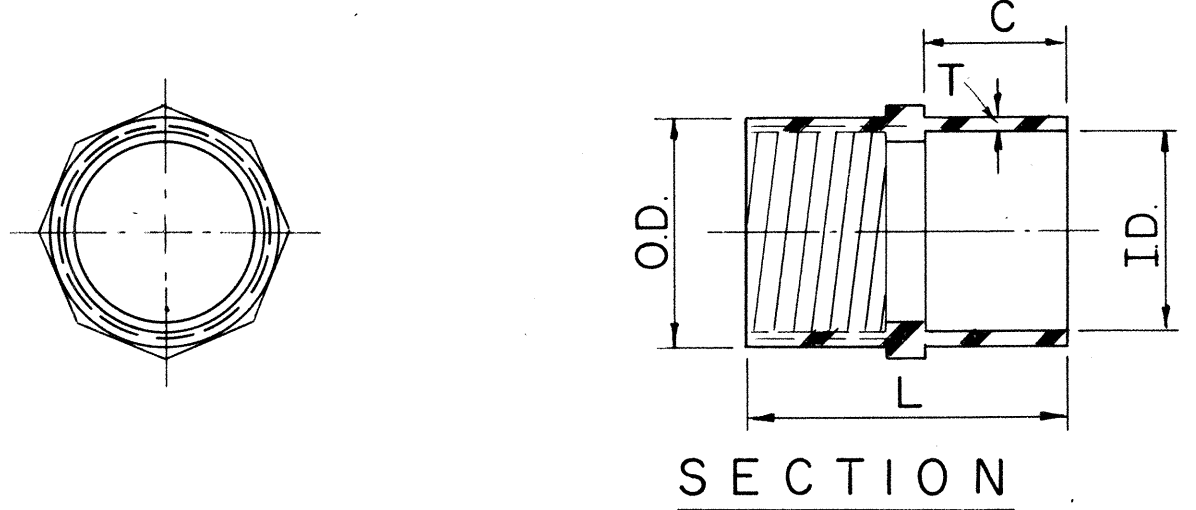


ADAPTER - PLASTIC TO STEEL

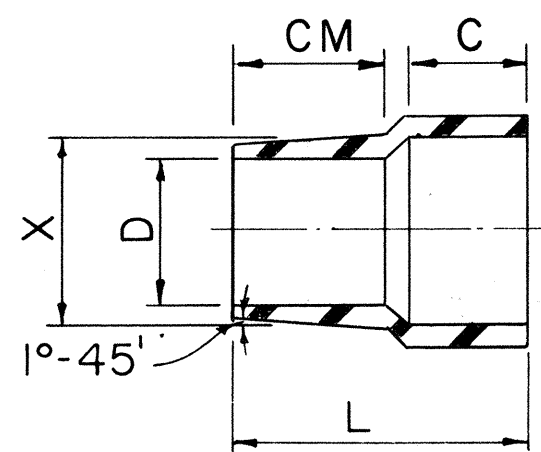

ADAPTER - PLASTIC TO ASBESTOS CEMENT

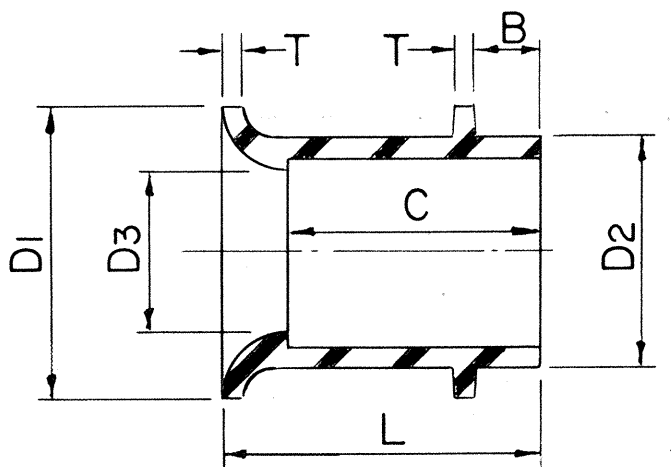

END BELL (ASTM D-2750)

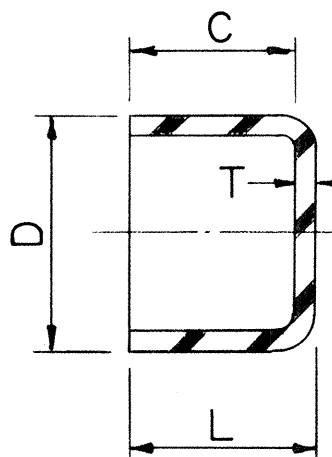

CAP (RIGID) - FOR SEMI-PERMANENT USE (ASTM D-2750)

CONDUIT SIZE	E B (ENCASED BURIAL)					DB (DIRECT BURIAL)				
	HECO CODE	O.D.	I.D.	T (MIN.)	WEIGHT #10 ² FT.	HECO CODE	O.D.	I.D.	T (MIN.)	WEIGHT #10 ² FT.
2		2.375	2.25	.060	21	29010	2.375	2.15	.110	38
3		3.500	3.35	.075	39	29012	3.500	3.25	.125	64
4		4.500	4.31	.095	63	29014	4.500	4.18	.160	104
5		5.563	5.36	.100	82	29016	5.563	5.20	.180	146
6		6.625	6.375	.125	121		6.625	6.25	.190	182

NOTE: Type EB & DB Conduits have same O.D. for a given size. All fittings which go over Conduits are DB type & fit both types of Conduits.


SIZE	HECO CODE	O.D.	D	L	C	S	T
2		2.620	2.255	2 7/16	1.16	.110	.110
3		3.780	3.350	3 3/8	1.63	.120	.125
4		4.855	4.310	3 11/16	1.78	.120	.160
5		5.965	5.363	4 3/32	1.97	.160	.180
6		7.050	6.375	4 15/32	2.16	.160	.190

SIZE	HECO CODE	O.D.	I.D.	L	T	C
2				2 15/16	1 1/16	1.16
3				3 7/16	1 5/8	1.63
4				3 11/16	1 23/32	1.78
5				4 1/16	1 27/32	1.97
6				4 15/8	1 11/16	3.44


SIZE	HECO CODE	L	X	C.M.	D	C
2		3 1/16	2.580	1 3/4	2.18	1.16
3		3 19/32	3.620	1 3/4	3.09	1.63
4		4 1/32	4.620	2	4.03	1.78
5						

SIZE	HECO CODE	D1	D2	D3	B	C	L	T
2		3.01	2.520	2.255	.50	1.16	1.54	.060
3		4.10	3.680	3.350	.75	1.63	2.00	.075
4		5.31	4.725	4.310	.75	1.78	2.28	.095
5		6.36	5.805	5.363	1.00	1.97	2.47	.100
6		7.38	6.920	6.375	1.00	2.16	2.66	.125

SIZE	HECO CODE	D	C	L	T
2		2.52	.59	.65	.060
3		3.68	.81	.89	.075
4		4.725	.91	1.01	.095
5		5.805	1.00	1.10	.100
6		6.920	1.13	1.25	.125

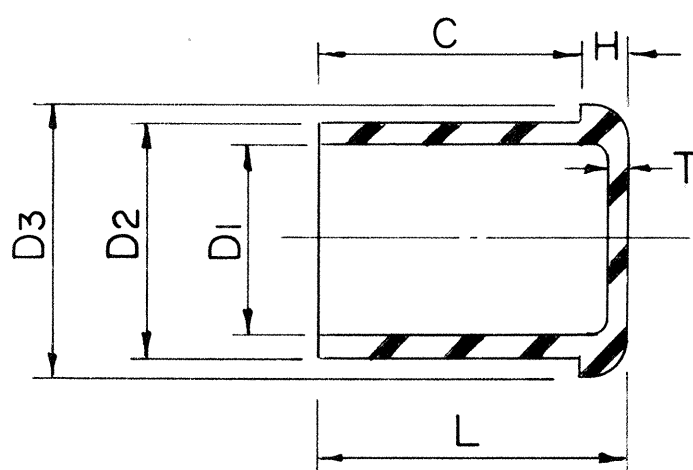


CAP (TEMPORARY) (ASTM D-2750)

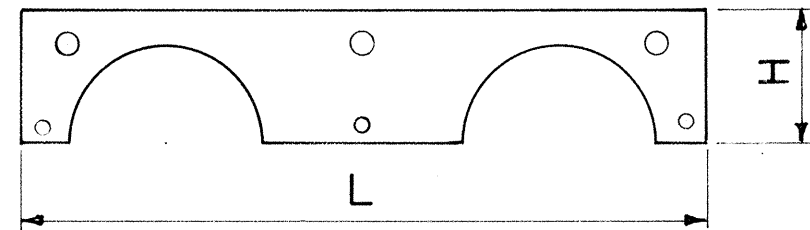


SIZE	HECO CODE	L	H
2		9.50	1.75
3		11.25	2.25
4		13.75	3.13
5		15.87	3.63
6		18.0	4.25

CAP SPACER

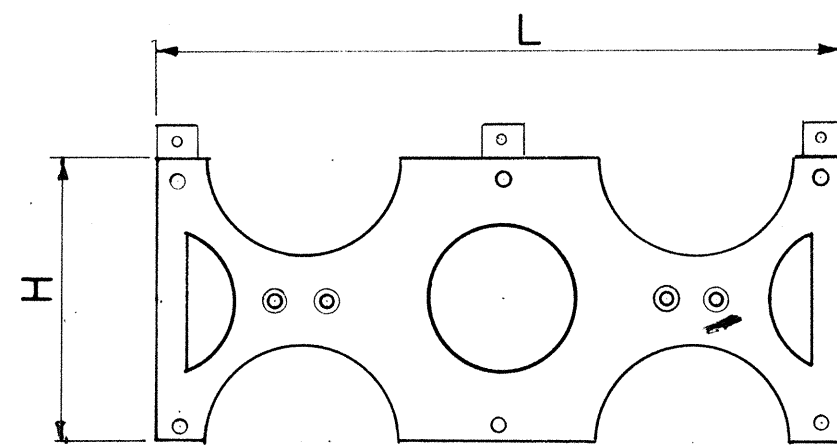


INTERMEDIATE SPACER

SIZE	HECO CODE	L	H	W
2		9.50	3.94	
3		11.25	5.06	
4		13.75	6.06	
5		15.97	7.06	
6		18.0	8.19	

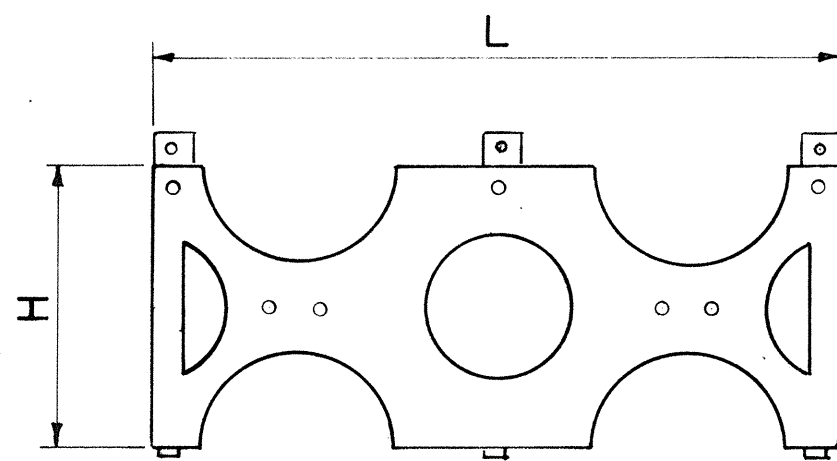

BASE SPACER

DUCT SPACER COMPONENTS (FORMEX SPACER OR EQUIVALENT)

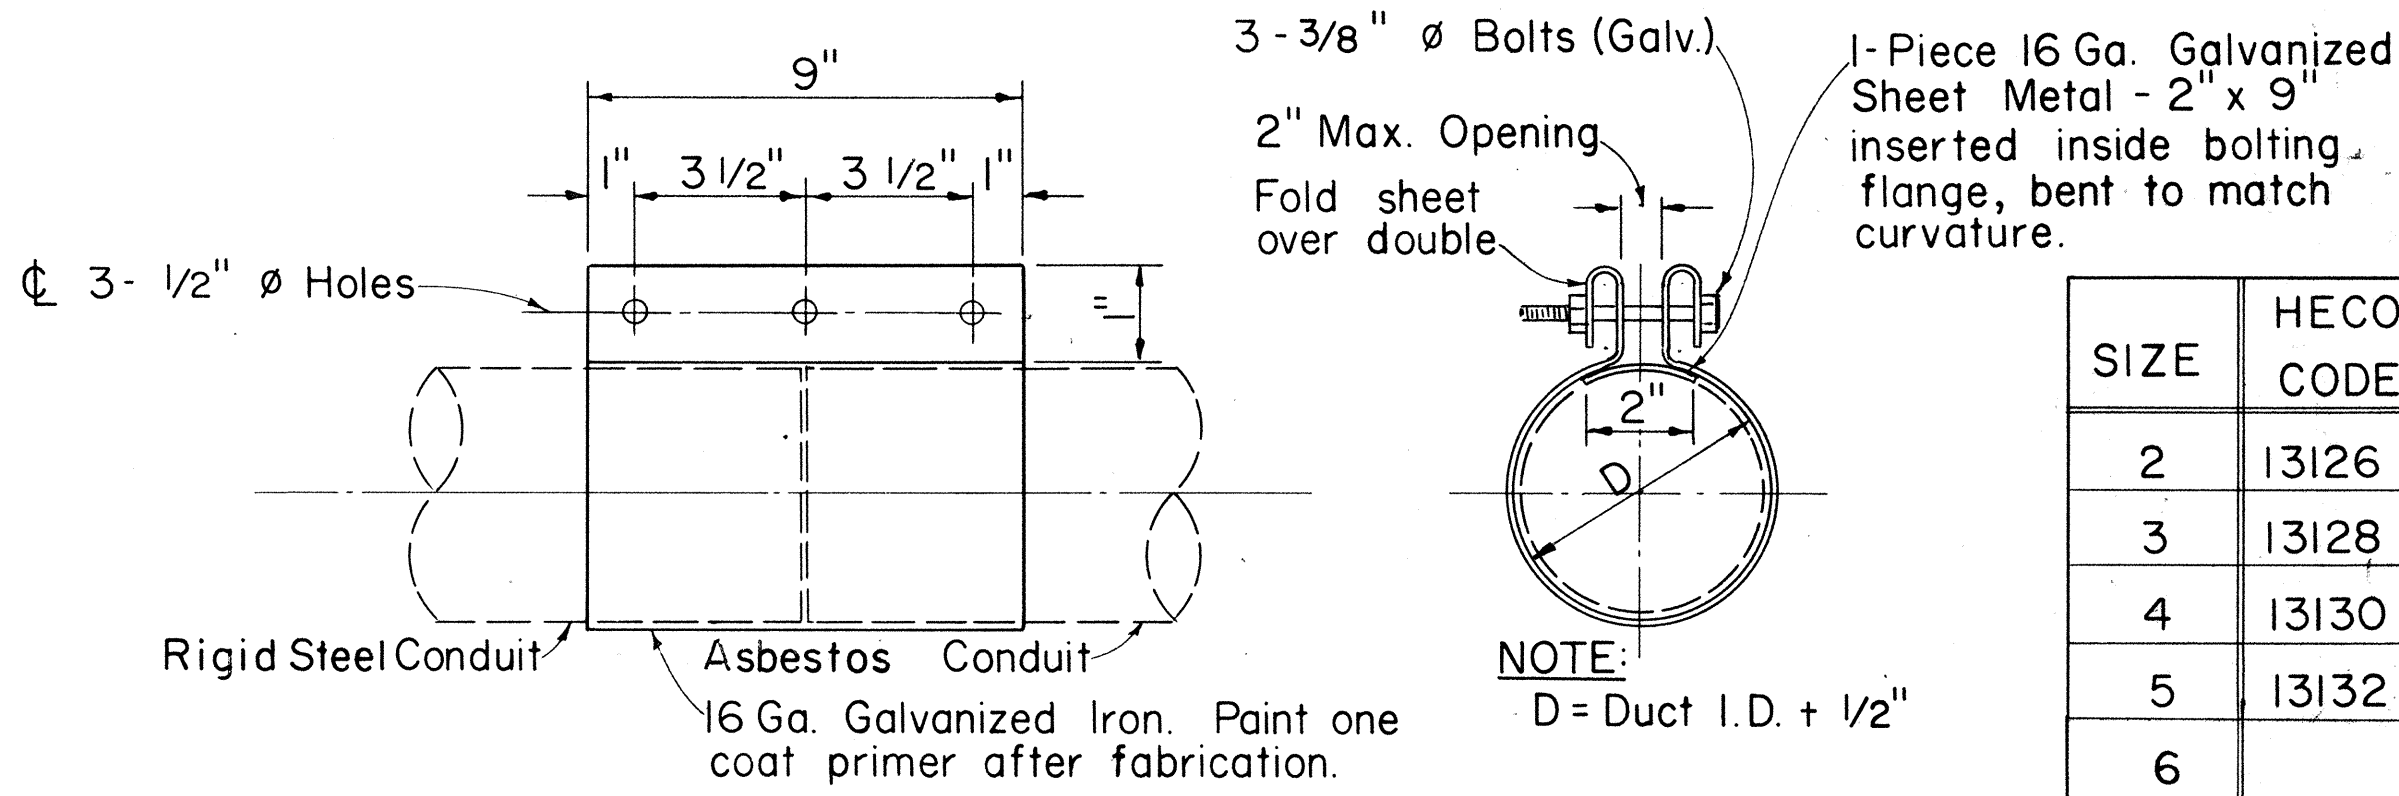

SIZE	HECO CODE
2	13126
3	13128
4	13130
5	13132
6	

3 - BOLT CLAMP

GENERAL NOTES:

- All dimensions in inches.
- Spacers shown are different than that used for Asbestos Cement Type.
- These accessories are to be used with ABS (Acrylonitrile-Butadiene-Styrene), or PVC (Poly-Vinyl Chloride) Plastic Conduit, per HECO purchase specification M7001-O.

APPROVED: *[Signature]* Date *8/10/77*
Hawaiian Electric Co., Inc.

SIZE	HECO CODE	D1	D2	D3	C	H	L	T
2		2.260	2.375	2.500	.593	.125	.718	.060
3		3.360	3.500	3.656	.812	.156	.968	.075
4		4.320	4.500	4.687	.906	.187	1.092	.095
5		5.375	5.638	5.760	1.000	.218	1.218	.100
6		6.390	6.625	6.875	1.093	.250	1.343	.125

NOTE: Cap will go over conduit or "plug" the coupling.

HECO, Inc. Drawing Number
30-1035-A SHEET NO. 2 OF 2 SHEETS

STATE OF HAWAII
DEPARTMENT OF TRANSPORTATION
LAND TRANSPORTATION FACILITIES DIVISION

STANDARD DETAILS
PLASTIC DUCTS
INSTALLATION DETAILS
UNDERGROUND STRUCTURES
(ELECTRIC)

Scales: Not to Scale

SHEET No. U-13 OF U-23 SHEETS

MSA 6 2.21-27



Scale: 2" = 1' - 0"

REFERENCE:
31" Manhole Frame -
Dwg. 011328.

4 - 3/4" Holes in Center of Flange at 90° (See Note)

3"

 
5/8"

8 Ribs See Detail "X"

B

B

Scale : 2" = 1'-0"



31" Manhole Cover - Dwg. 011327.

Scale: As Shown

4-5/8" ϕ x 8" Long galv. machine bolts
to secure manhole cover frame
see HECO DWG. 011328 on this sheet.

3"

4 ea. 5/8" ϕ x 6"
Long galv. mach.
bolts w/ Sq. nuts

3"

A

HALF PLAN
N.T.S

Manhole Frame per
HECO DWG. 011328

Final finish Grade

1'-0" Max.
1" Grout
4"
6"
collar $\approx$ 3'-0"

1 1/2"
2"

2" 3" 2"

4 ea. 5/8" ϕ , 6" long galv.
mach. bolts with square
nuts

#4 Hoops at 12" $\square$

#4 at 12" L

Contractor to furnish and install
4 each Galvanized Eyelet.
1 1/4" x 3" Eyeslot; 11/16" Hole

SECTION A-A
N.T.S

(For Manhole Collar equal or greater than 3'-0")


SHEET No. U-14 OF U-23 SHEETS

011328

186


WF-43

FED. ROAD DIST. NO.	STATE	FED. AID PROJ. NO.	FISCAL YEAR	SHEET NO.	TOTAL SHEETS
HAWAII	HAW.	1-H-1(131)17	1977	187	394

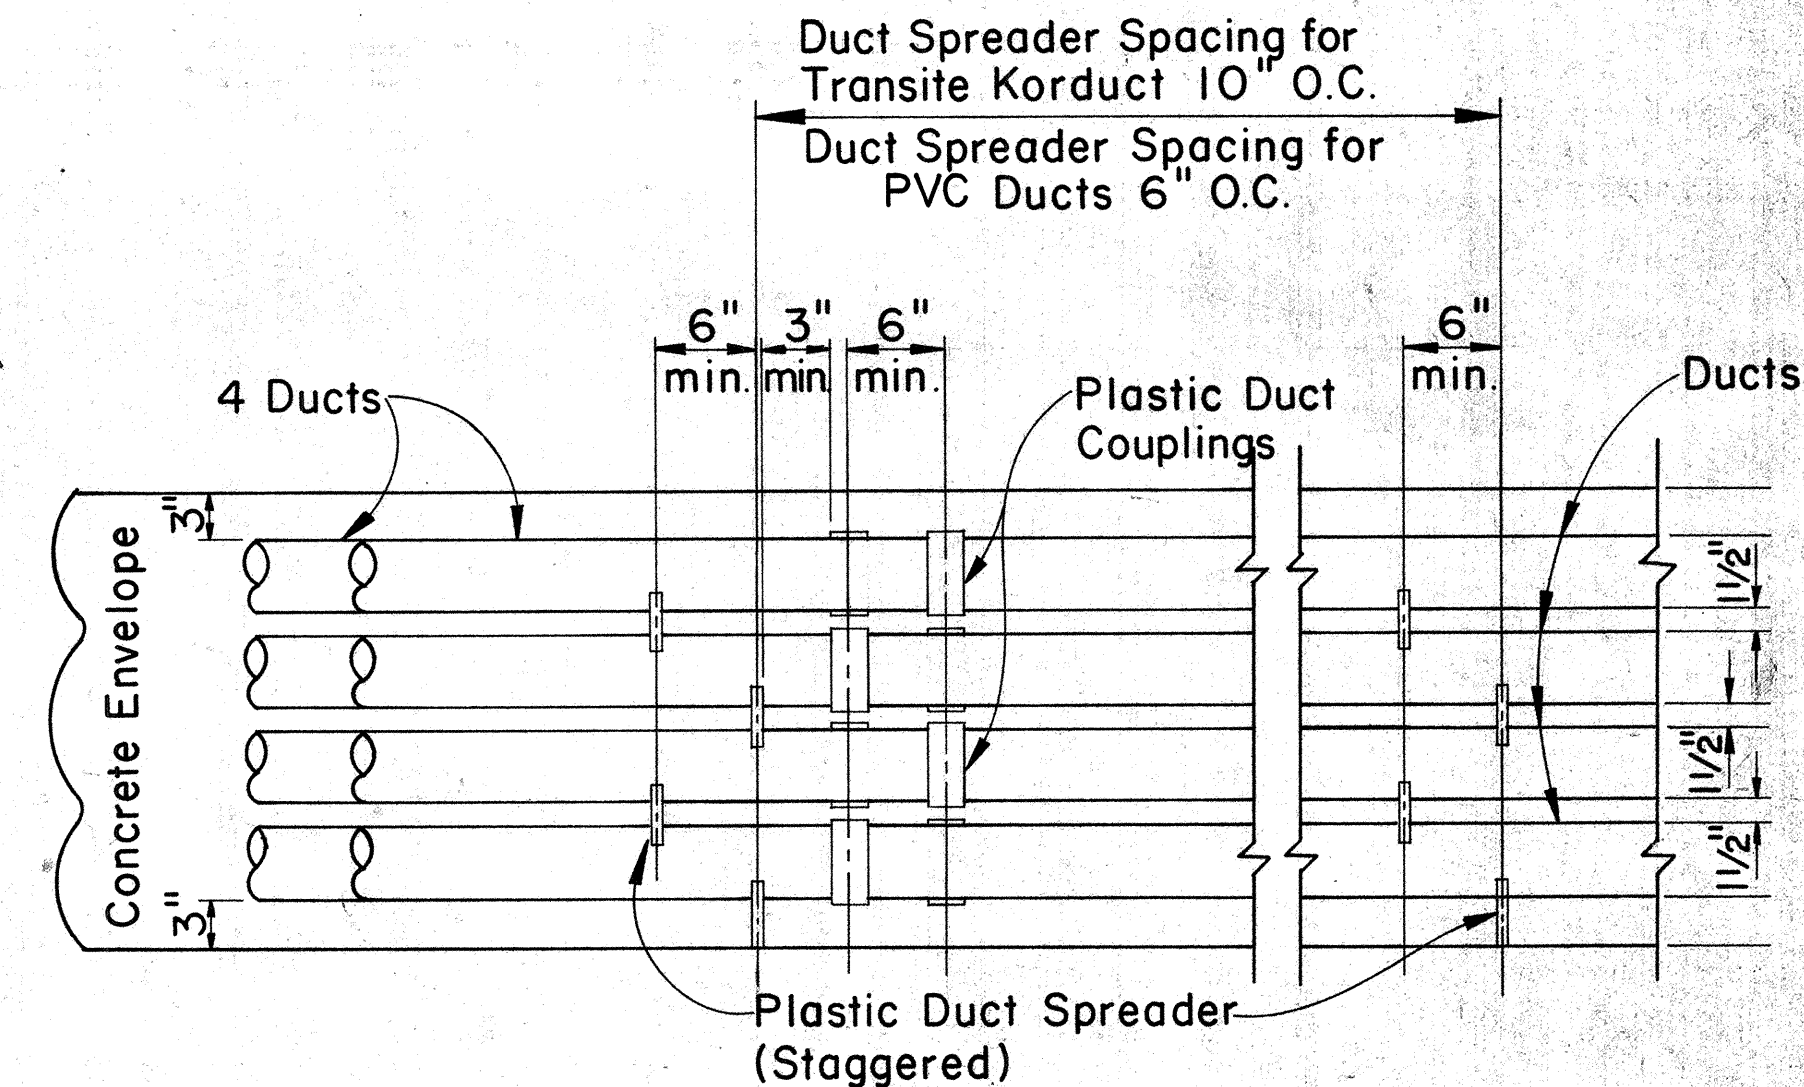

TYPICAL DUCT ENVELOPE ELEVATION ARRANGEMENT OF COUPLING & PLASTIC SPACERS

Scale: 1" = 1'-0"

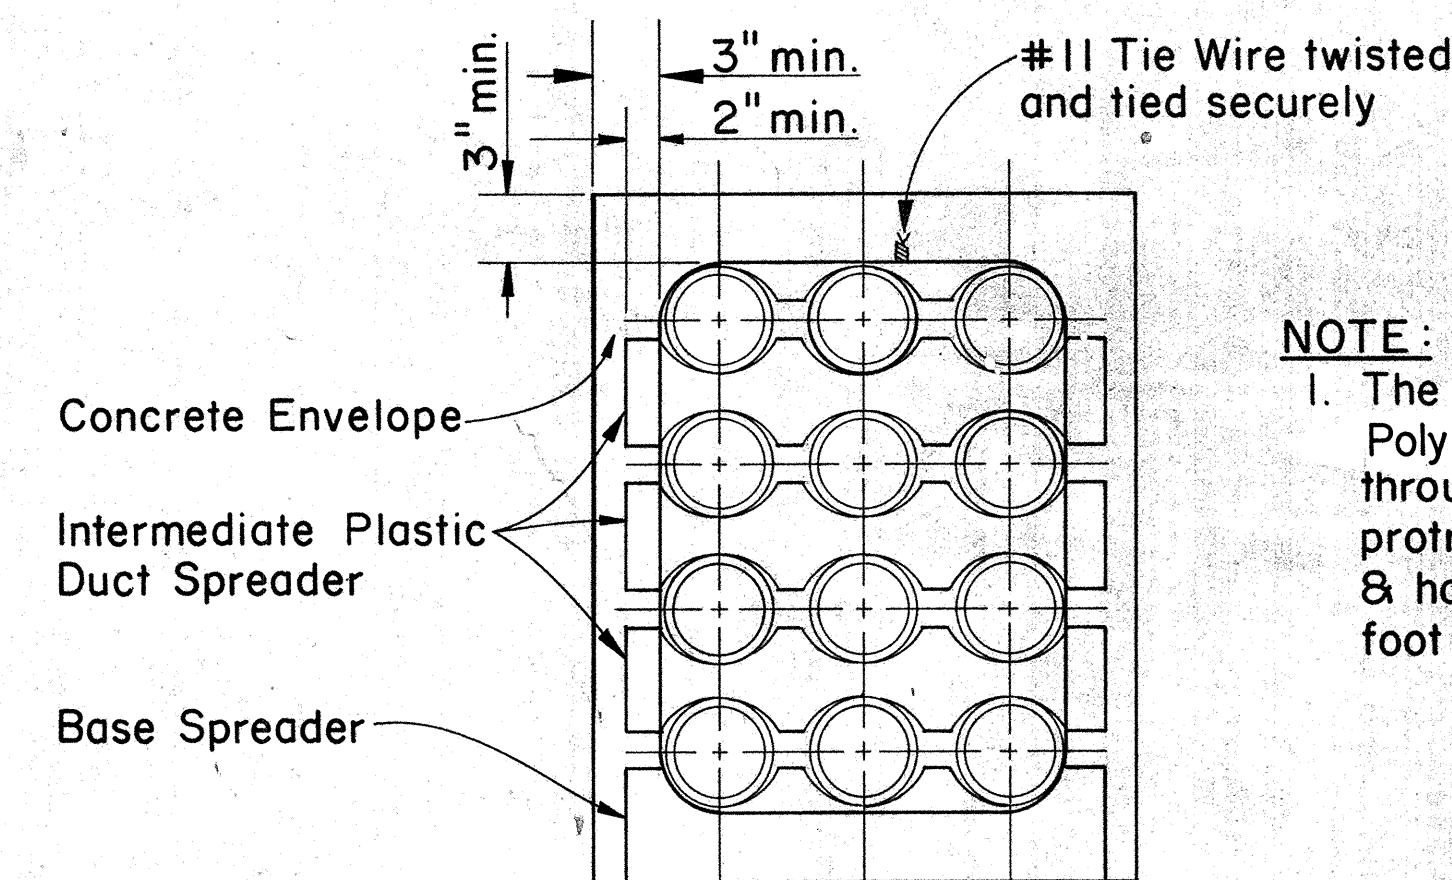

NOTE:
1. The Contractor shall place 1/8" Poly Pull Line in designated duct throughout its entire length with protrusions of 2 feet in manholes & handholes at each end and 1 foot in pullboxes.


SECTION SHOWING SPACERS

Scale: 1 1/2" = 1'-0"

Denotes H.T. Co.
 $\left(\frac{T}{20F-4}\right)$
Denotes Number of ducts bottom layer
Denotes 4 inch ducts
Denotes Total Number Of Ducts


SYMBOL IDENTIFICATION

APPROVED:	
<i>K. Yoshikawa</i>	8-15-77
Hawaiian Telephone Co.,	Date
H.T. Co.,	Drawing No. 34028-A
STATE OF HAWAII DEPARTMENT OF TRANSPORTATION LAND TRANSPORTATION FACILITIES DIVISION	
STANDARD DUCT FORMATIONS (TELEPHONE)	
Scale: As Shown	Date: Aug. 31, 1977
SHEET No. 11-15 OF 11-23 SHEETS	

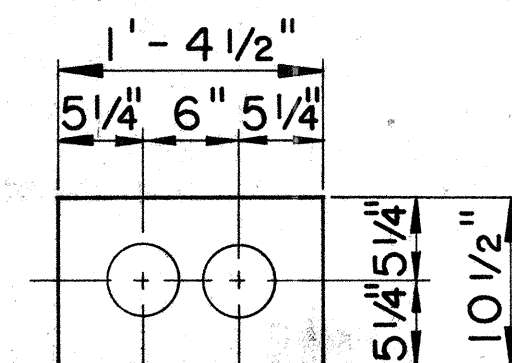


2 DUCTS

$$\left(\frac{T}{2F-2}\right)$$

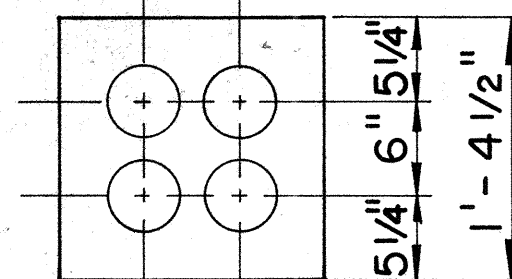


2 WIDE X 2 HIGH

$$\left(\frac{T}{4F-2}\right)$$

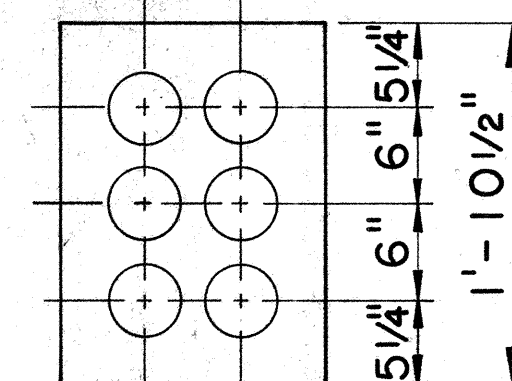


2 WIDE X 3 HIGH

$$\left(\frac{T}{6F-2}\right)$$

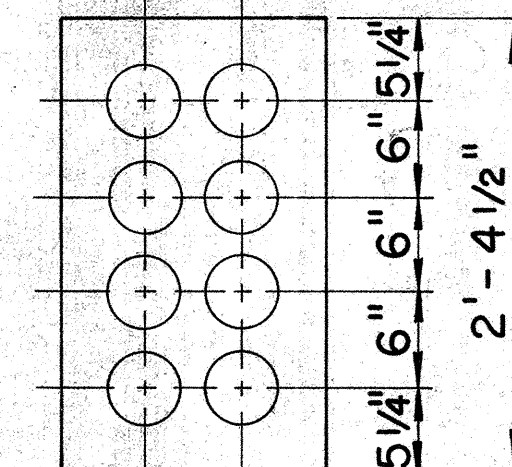


2 WIDE X 4 HIGH

$$\left(\frac{T}{8F-2}\right)$$

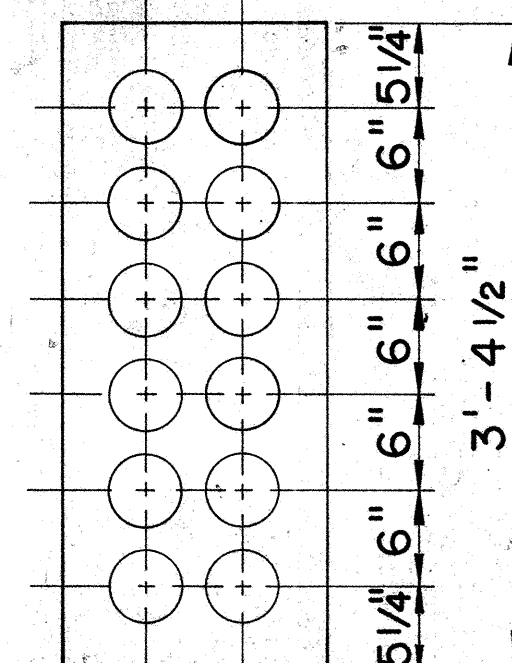


2 WIDE X 6 HIGH

$$\left(\frac{T}{12F-2}\right)$$

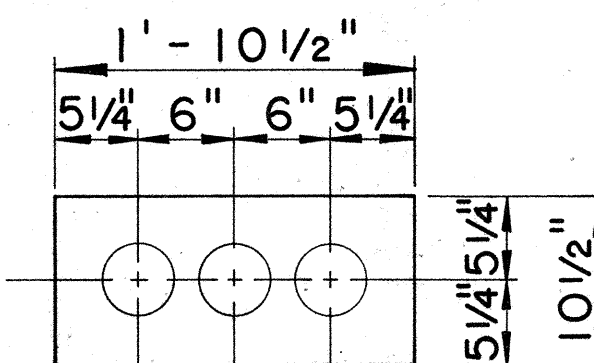


3 DUCTS

$$\left(\frac{T}{3F-3}\right)$$

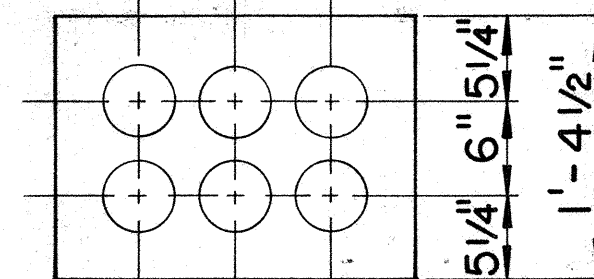


3 WIDE X 2 HIGH

$$\left(\frac{T}{6F-3}\right)$$

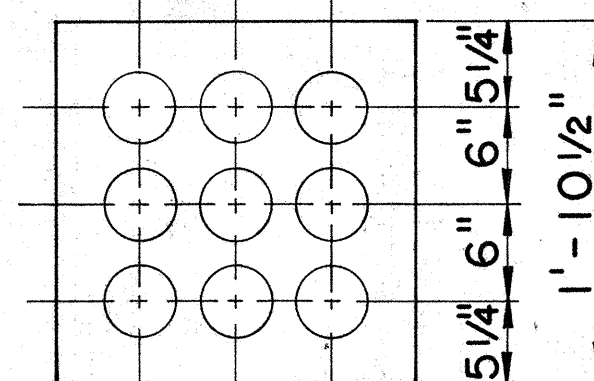


3 WIDE X 3 HIGH

$$\left(\frac{T}{9F-3}\right)$$

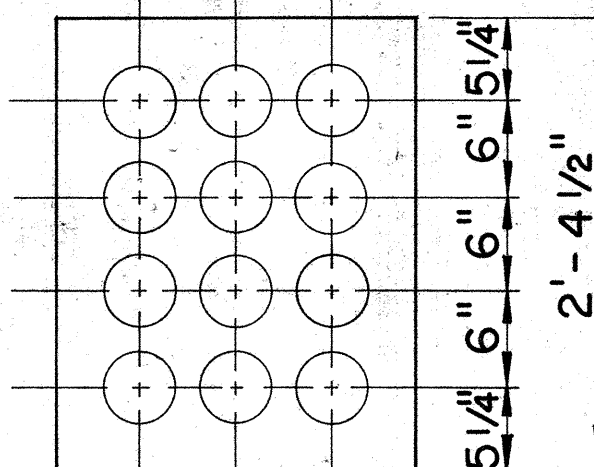


3 WIDE X 4 HIGH

$$\left(\frac{T}{12F-3}\right)$$

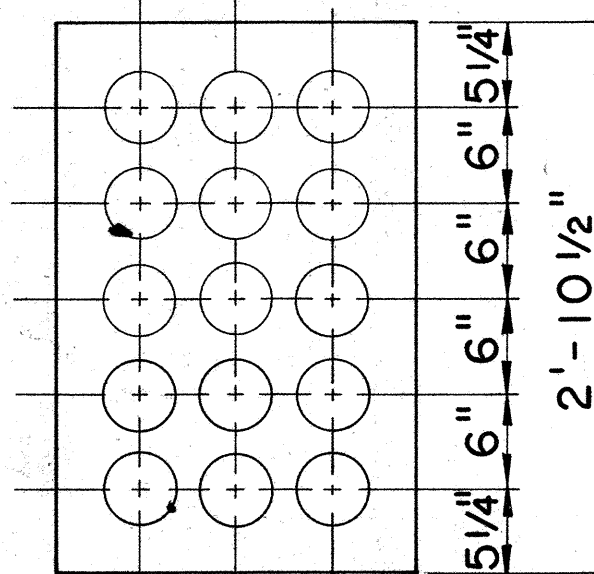


3 WIDE X 5 HIGH

$$\left(\frac{T}{15F-3}\right)$$

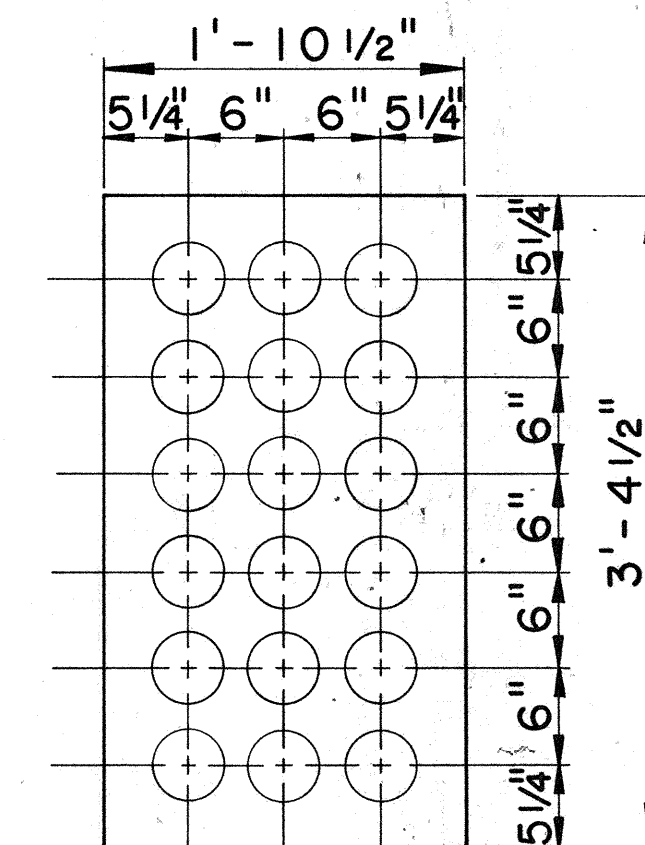


3 WIDE X 6 HIGH

$$\left(\frac{T}{18F-3}\right)$$

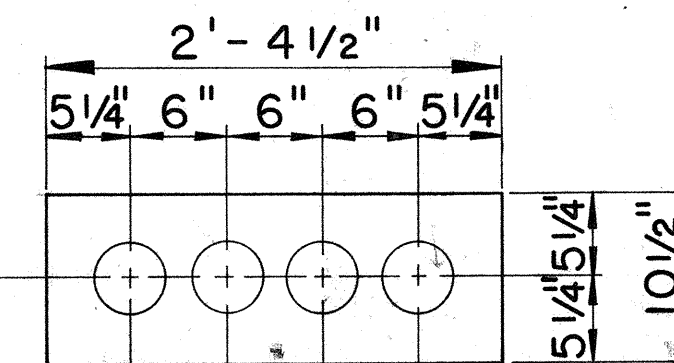


4 DUCTS

$$\left(\frac{T}{4F-4}\right)$$

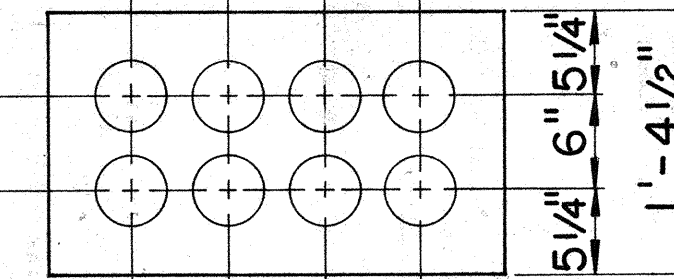


4 WIDE X 2 HIGH

$$\left(\frac{T}{8F-4}\right)$$

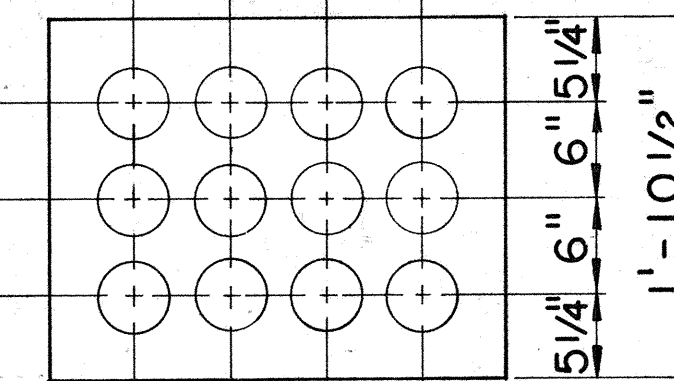


4 WIDE X 3 HIGH

$$\left(\frac{T}{12F-4}\right)$$

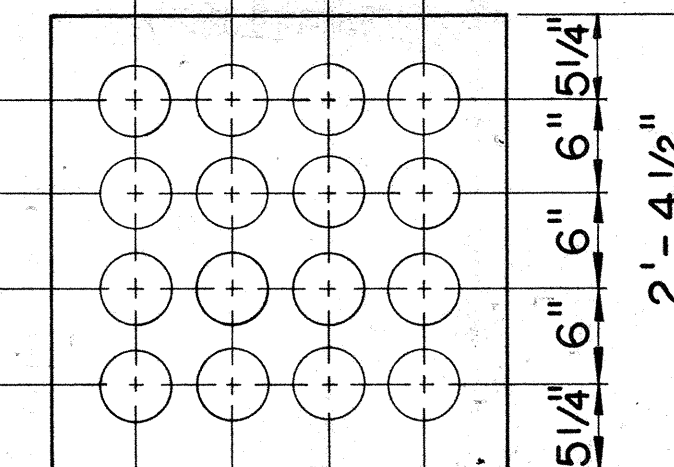

4 WIDE X 4 HIGH

$$\left(\frac{T}{16F-4}\right)$$

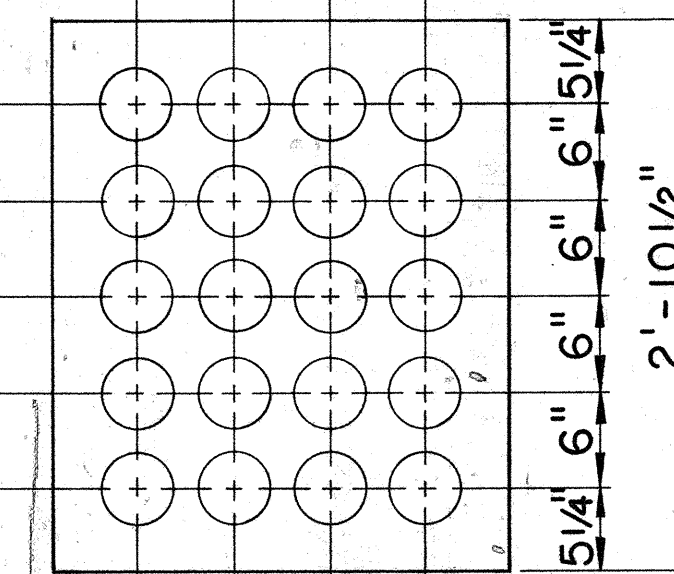

4 WIDE X 5 HIGH





$$\left(\frac{T}{20F-4}\right)$$

STANDARD DUCT FORMATIONS

Scale: 1" = 1'-0"

ORIGINAL PLAN	DATE
DRAWN BY	
DESIGNED BY	
NOTE BOOK	
QUANTITIES BY	
CHECKED BY	
No.	

FED. ROAD DIST. NO.	STATE	FED. AID PROJ. NO.	FISCAL YEAR	SHEET NO.	TOTAL SHEETS
HAWAII	HAW.	I-H1-1(131):17	1977	188	394

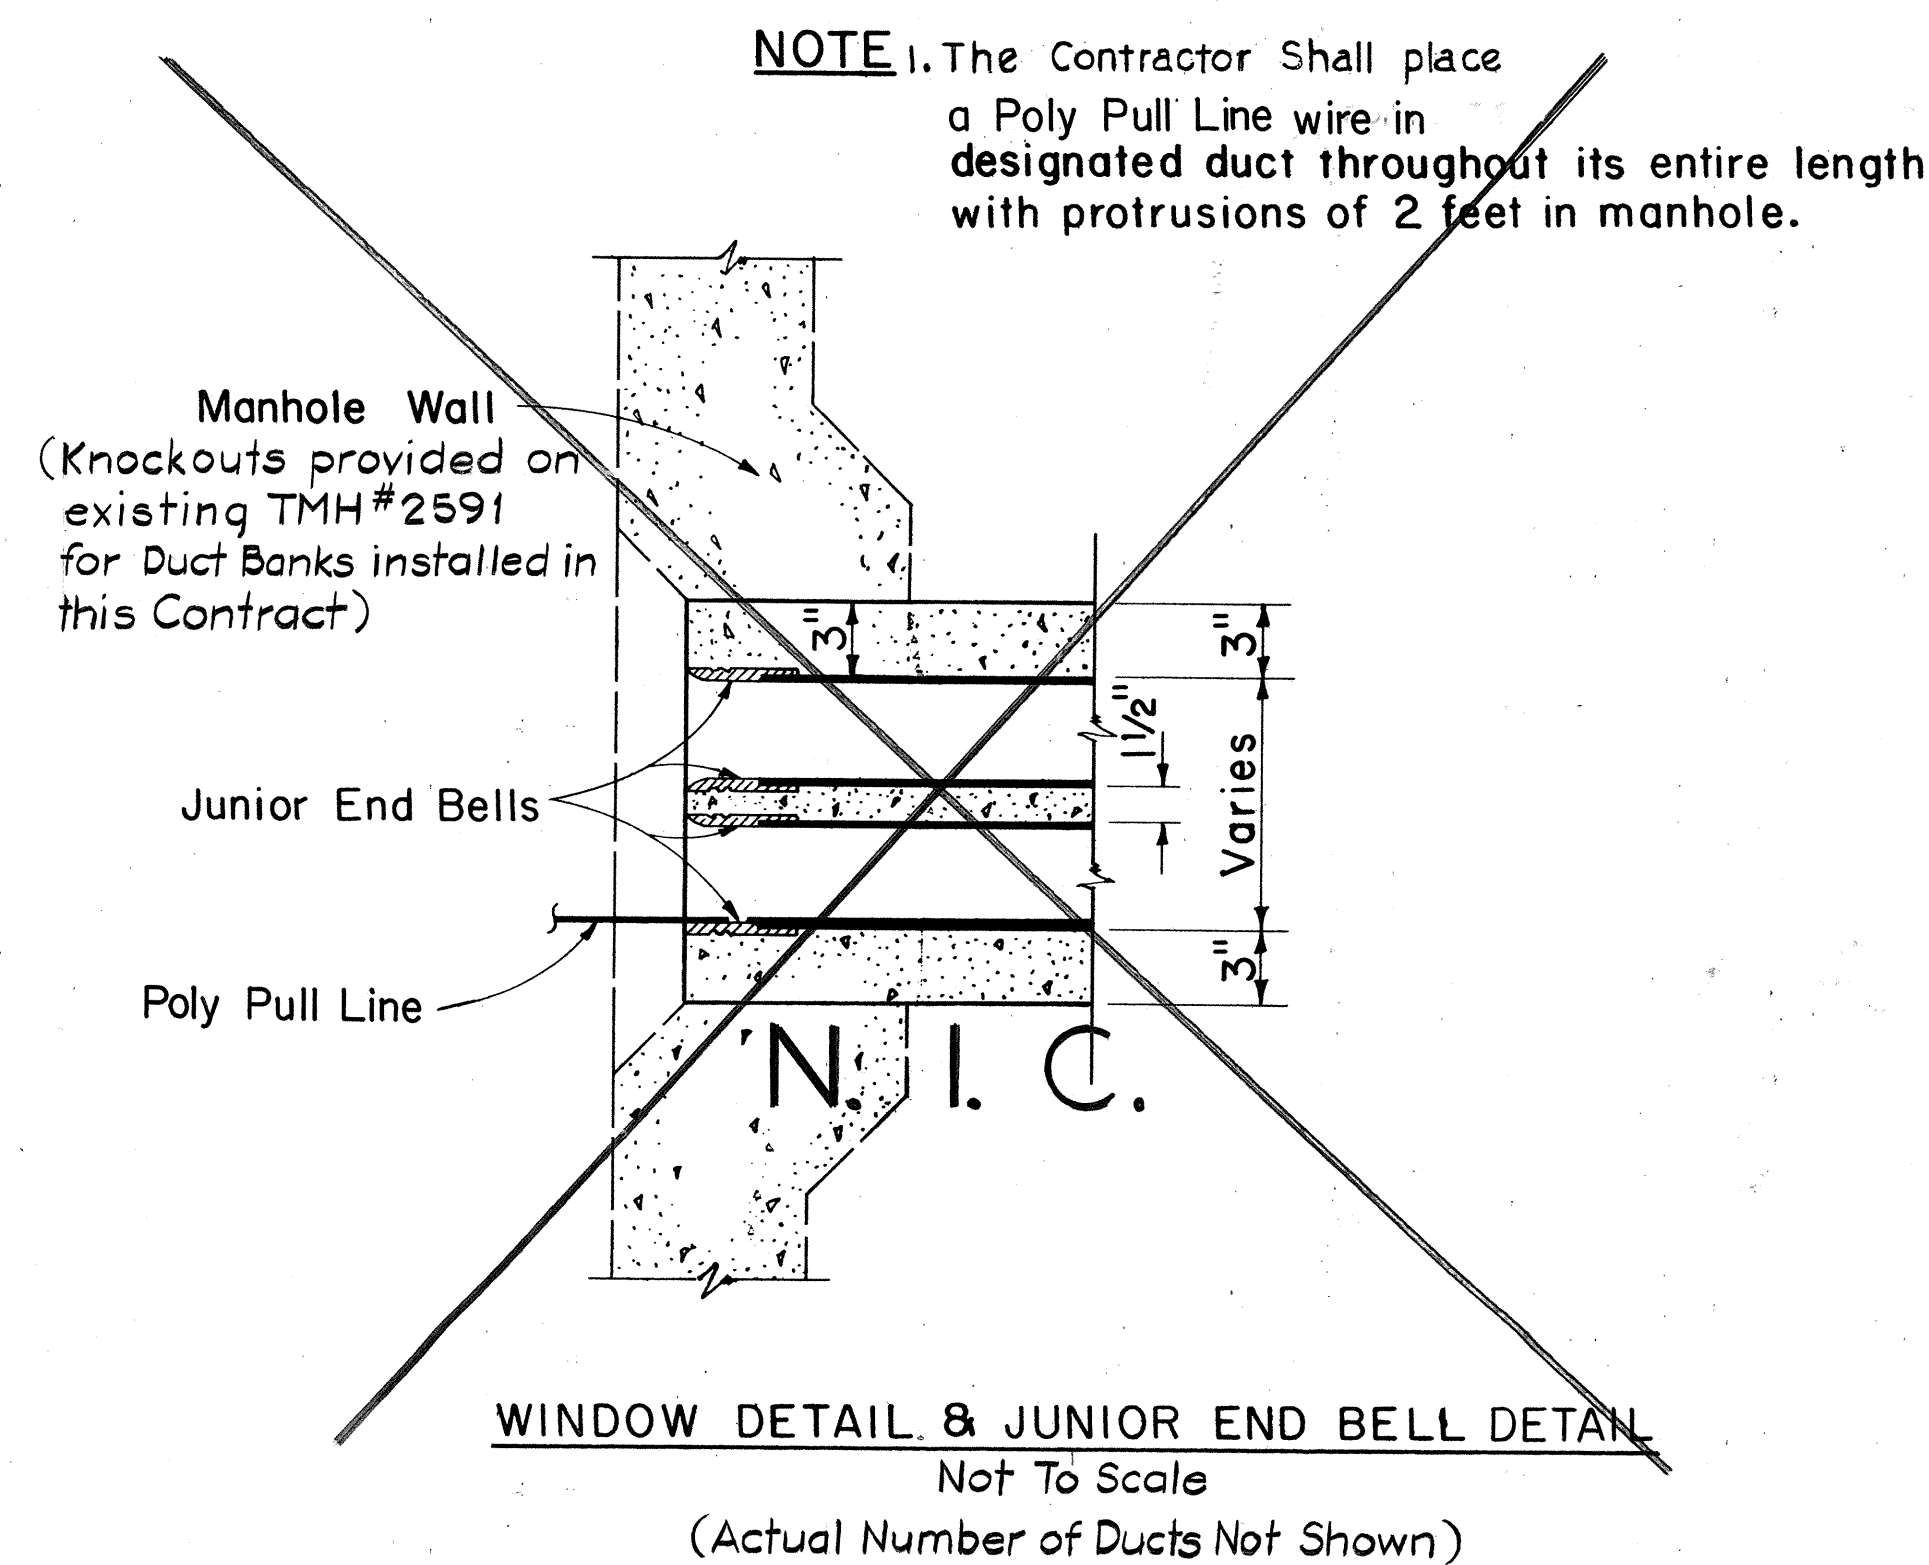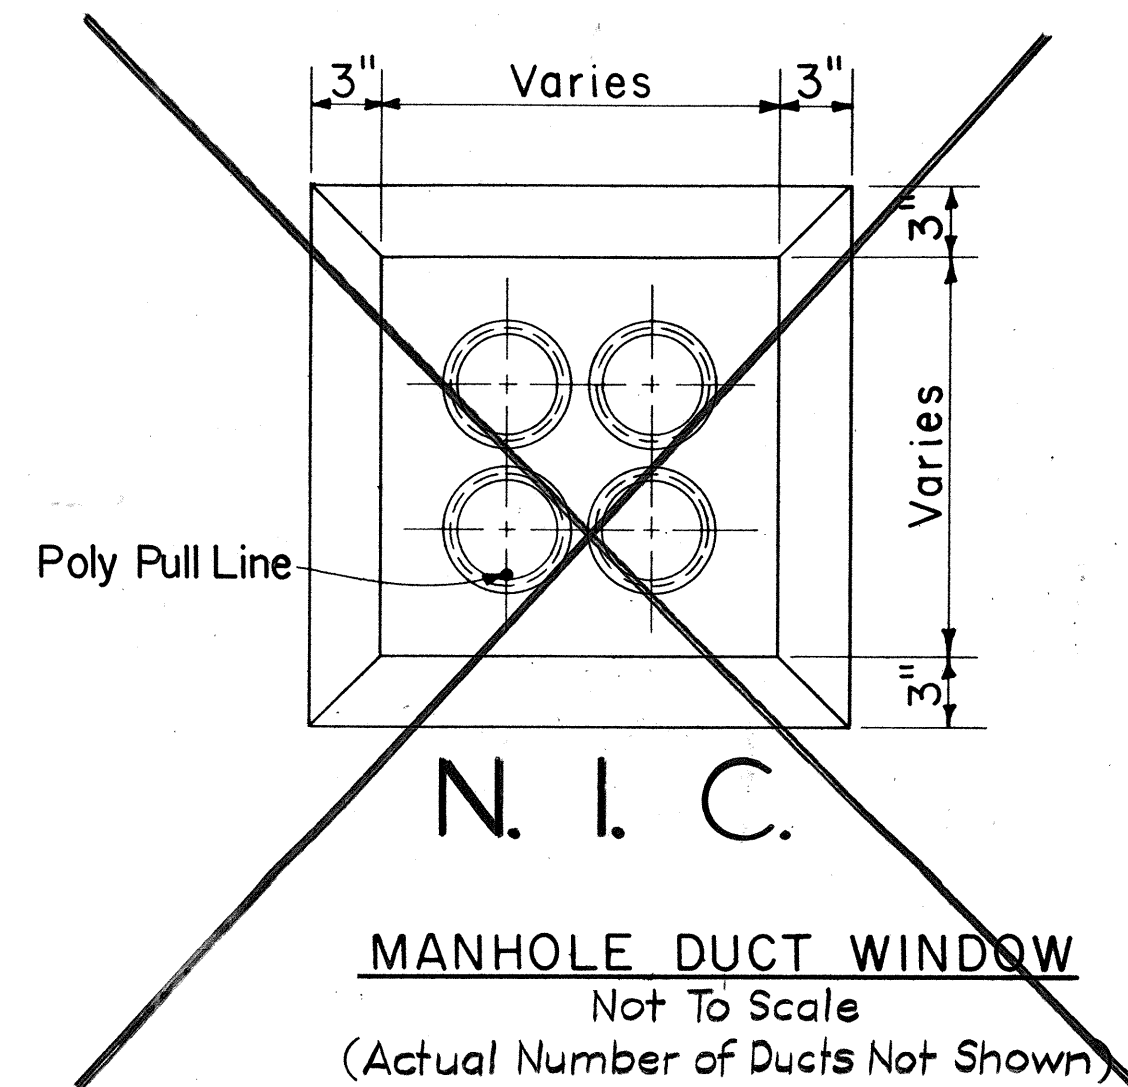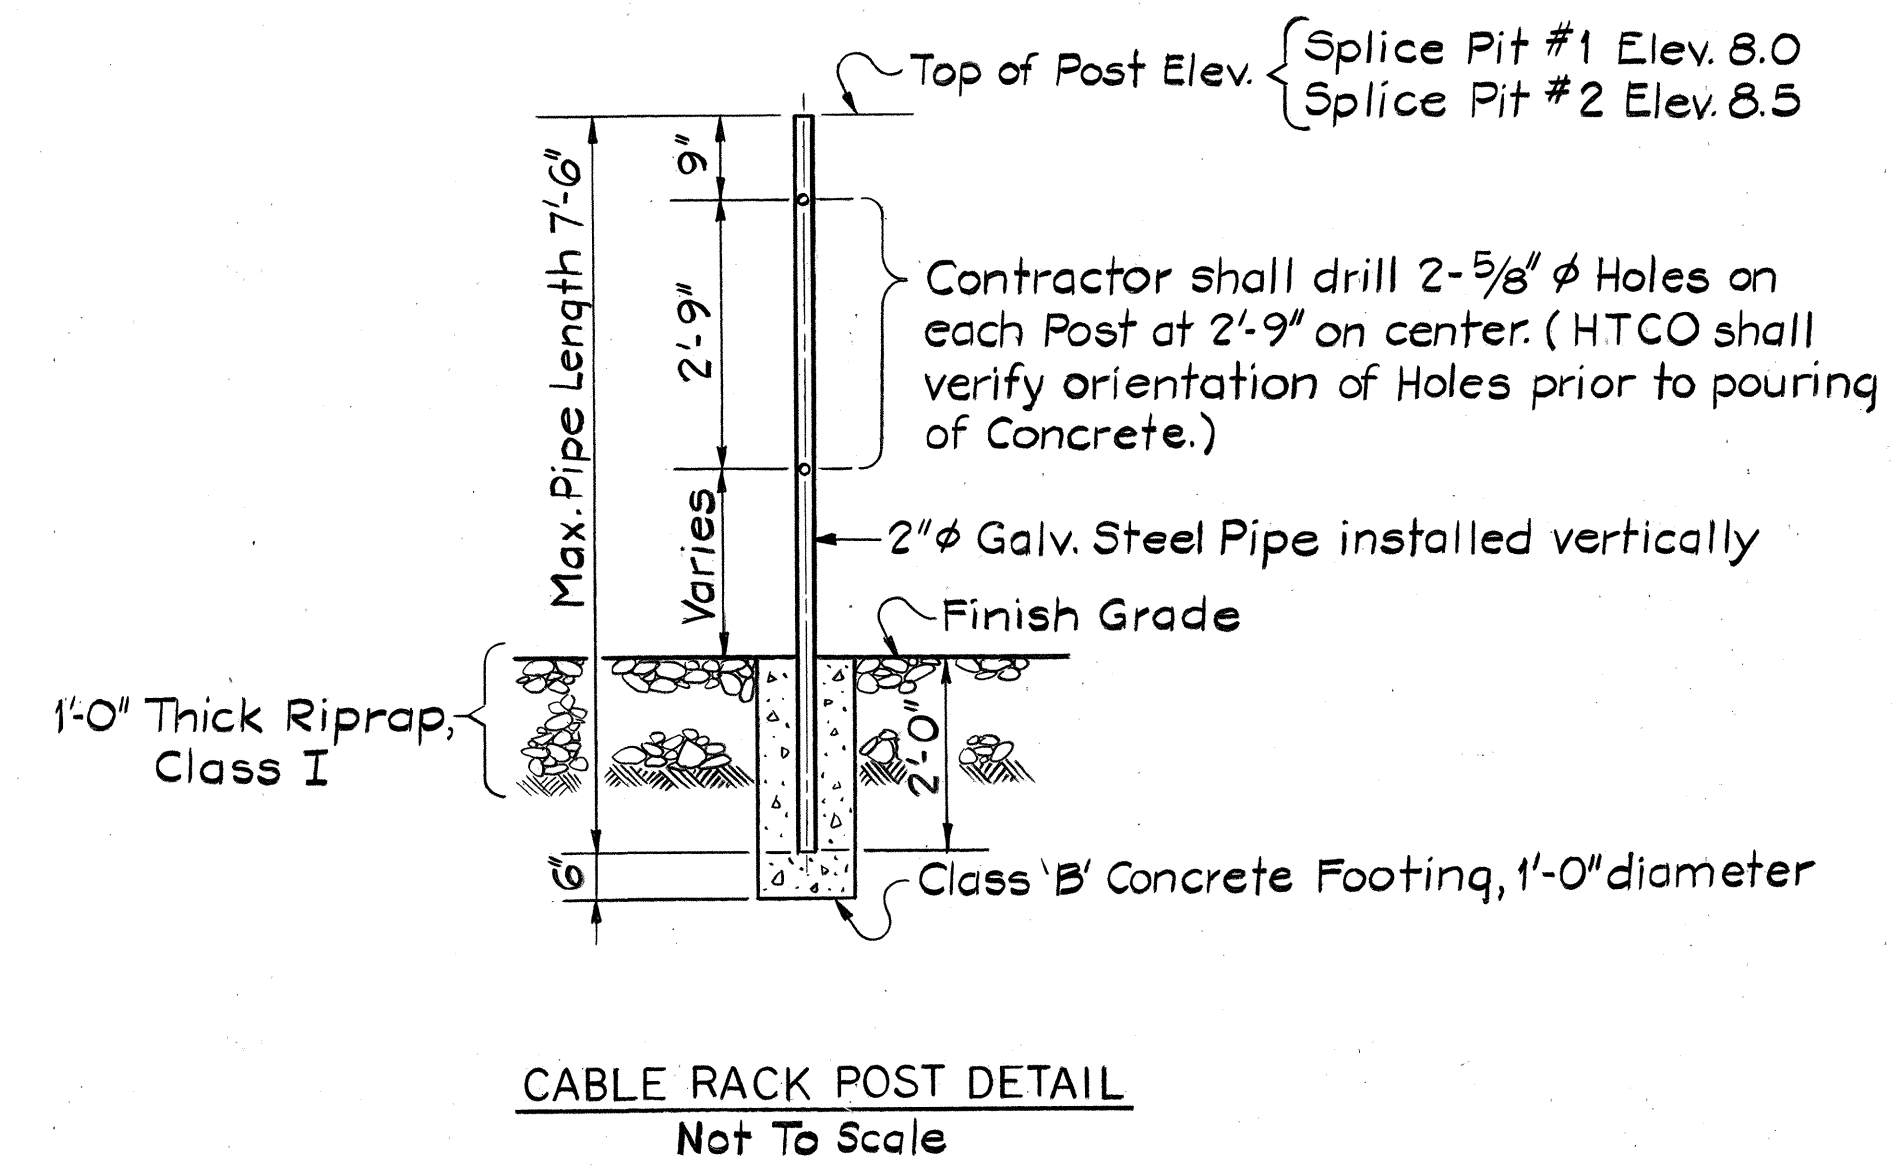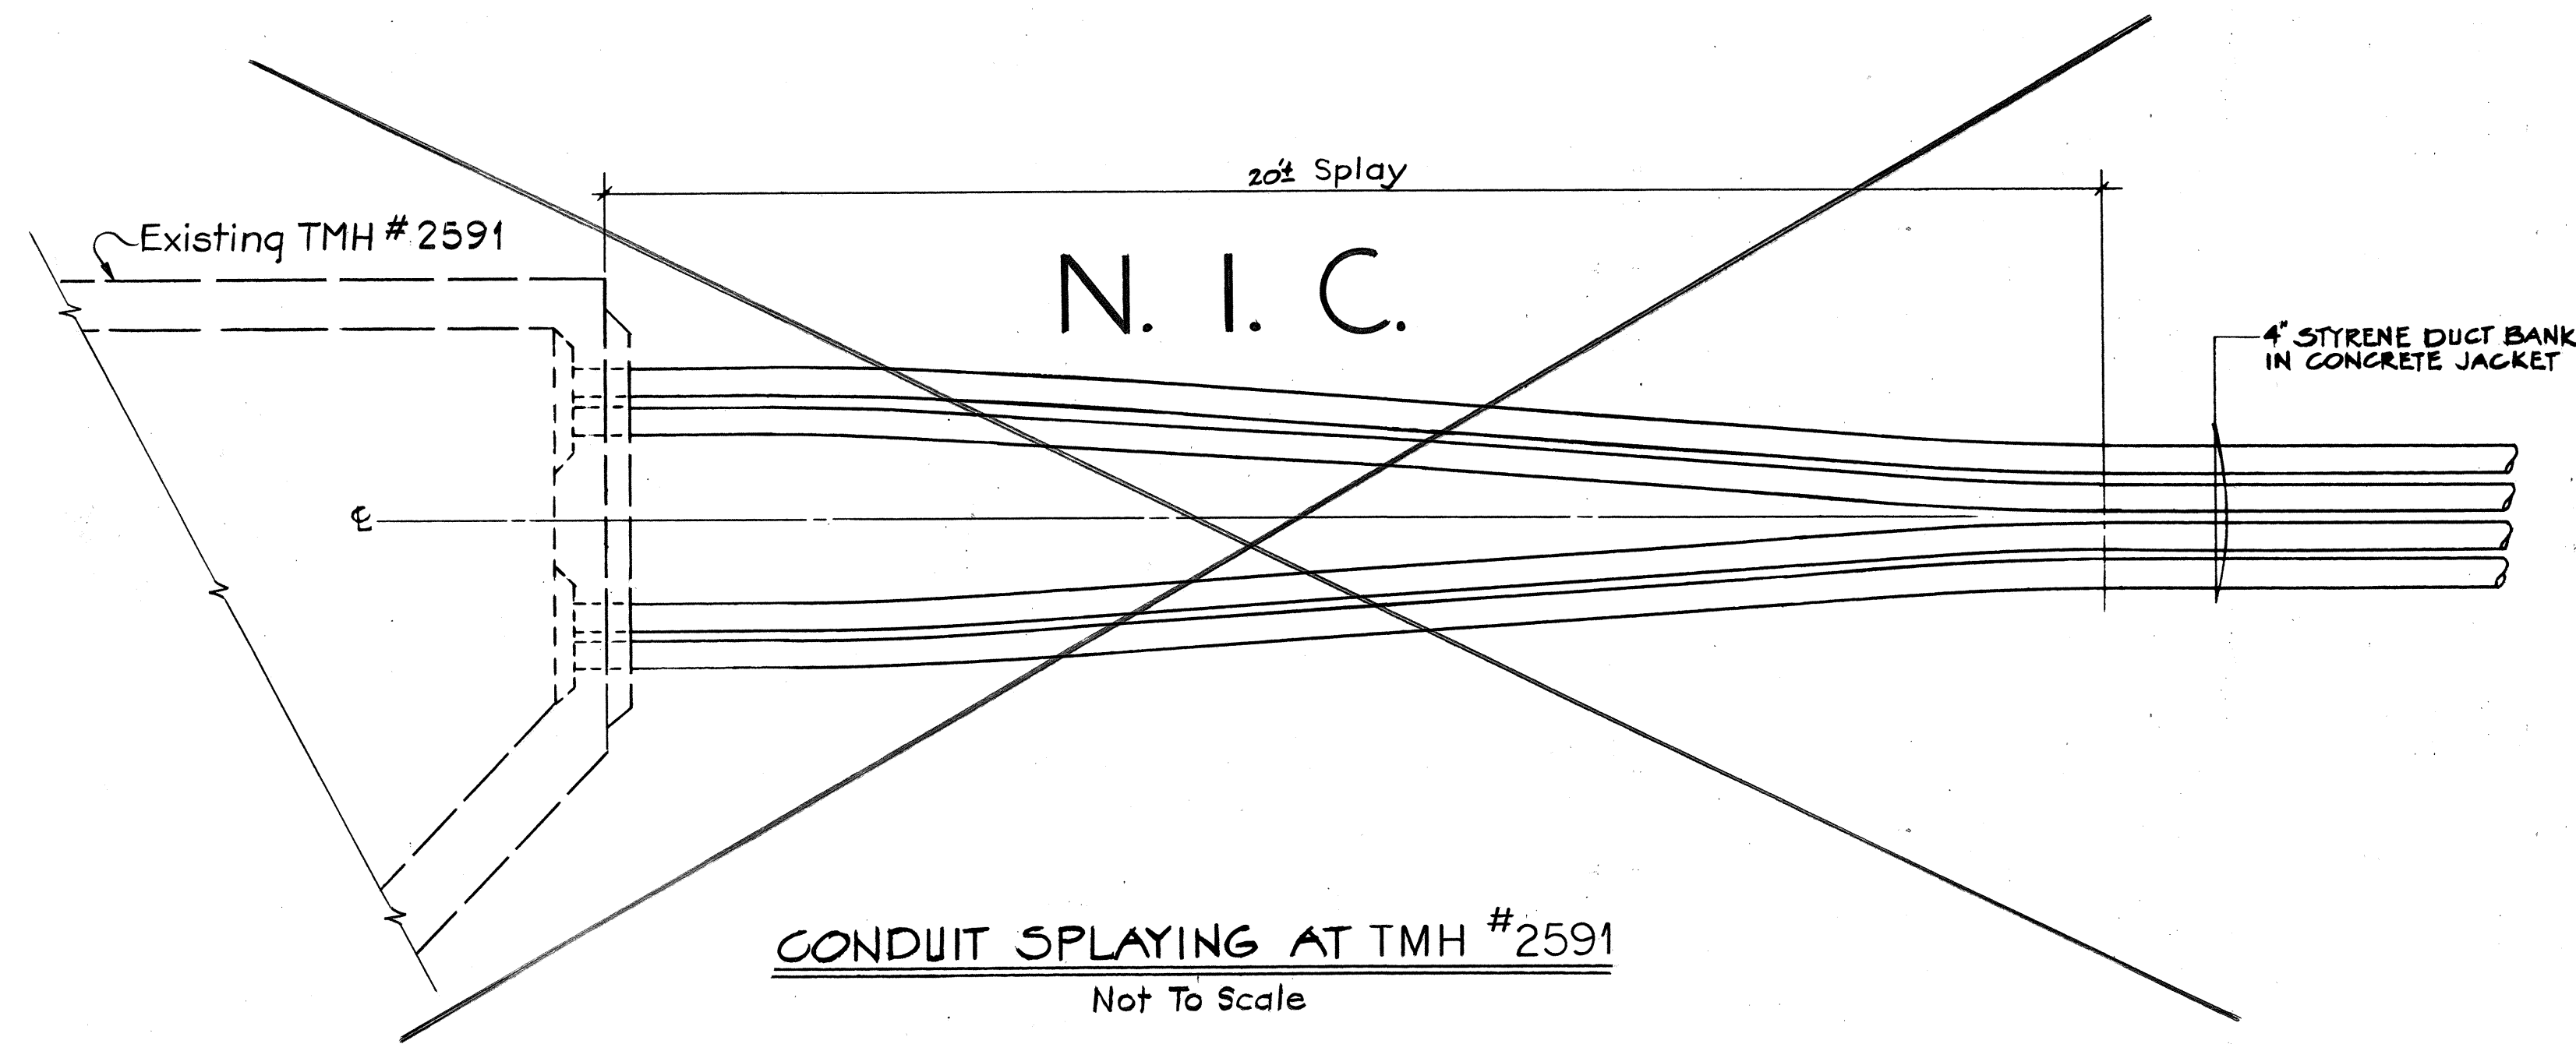


APPROVED:
B. [Signature]
 HAWAIIAN TELEPHONE CO.,
 DATE: 8-15-77


WERNER BEUGGER
 REGISTERED
 PROFESSIONAL
 ENGINEER
 No. 3383-E
 HAWAII, U.S.A.
 THIS WORK WAS PREPARED BY ME
 OR UNDER MY SUPERVISION.
Werner Beugger

STATE OF HAWAII
 DEPARTMENT OF TRANSPORTATION
 HIGHWAYS DIVISION
 MISCELLANEOUS TELEPHONE
 DETAILS
 INTERSTATE ROUTE H-1
 PROJECT NO. I-H1-1(131):17
 SCALE: AS SHOWN DATE: AUG. 31, 1977
 SHEET No. U-16 OF U-23 SHEETS


FED. ROAD DIST. NO.	STATE	FED. AID PROJ. NO.	FISCAL YEAR	SHEET NO.	TOTAL SHEETS
HAWAII	HAW.	I-HI-1(131):17	1977	189	394

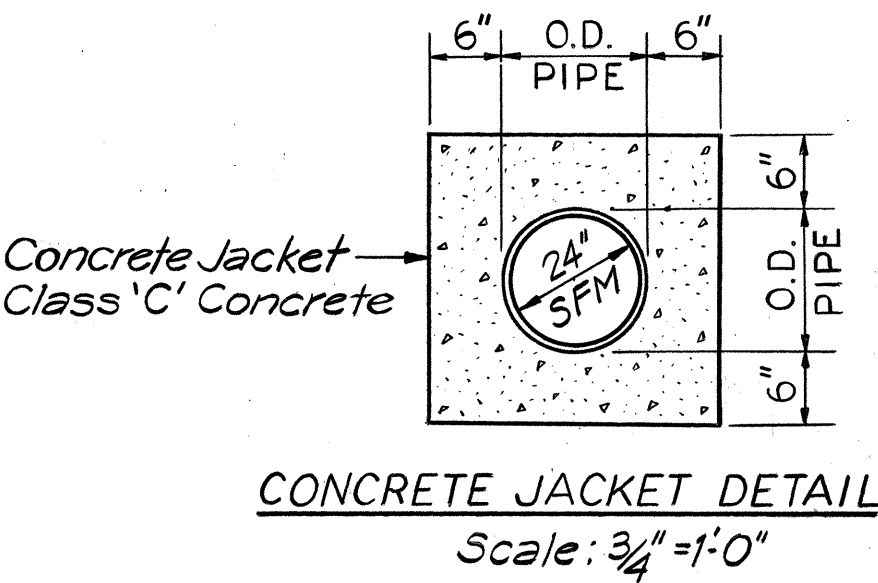


- NOTES:**
1. The Contractor shall notify Mr. Sanford Haseyama (Tel. 438-1394) of Directorate of Facilities Engineering fourteen (14) days prior to commencement of sewer work. Interruptions to the sewage pumping station's operations shall be coordinated with Mr. Haseyama.
 2. The Contractor shall have two work crews, one at each end of the line to make the connection simultaneously. If the Contractor is not properly prepared, the scheduled outage shall be cancelled. The Contractor shall be allowed a maximum shutdown time of 6 hours between midnight and 6:00 A.M. to make the connections into the existing main.
 3. In the event that any changes in alignment or grade for the proposed sewer are required due to unforeseen obstacles the Contractor shall immediately notify the Engineer and provide the Engineer the necessary data in order that the Engineer will be able to determine what changes in alignment or grade are required.
 4. Working pressure of the sewer main is 15 psi. Test pressure shall be 25 psi.

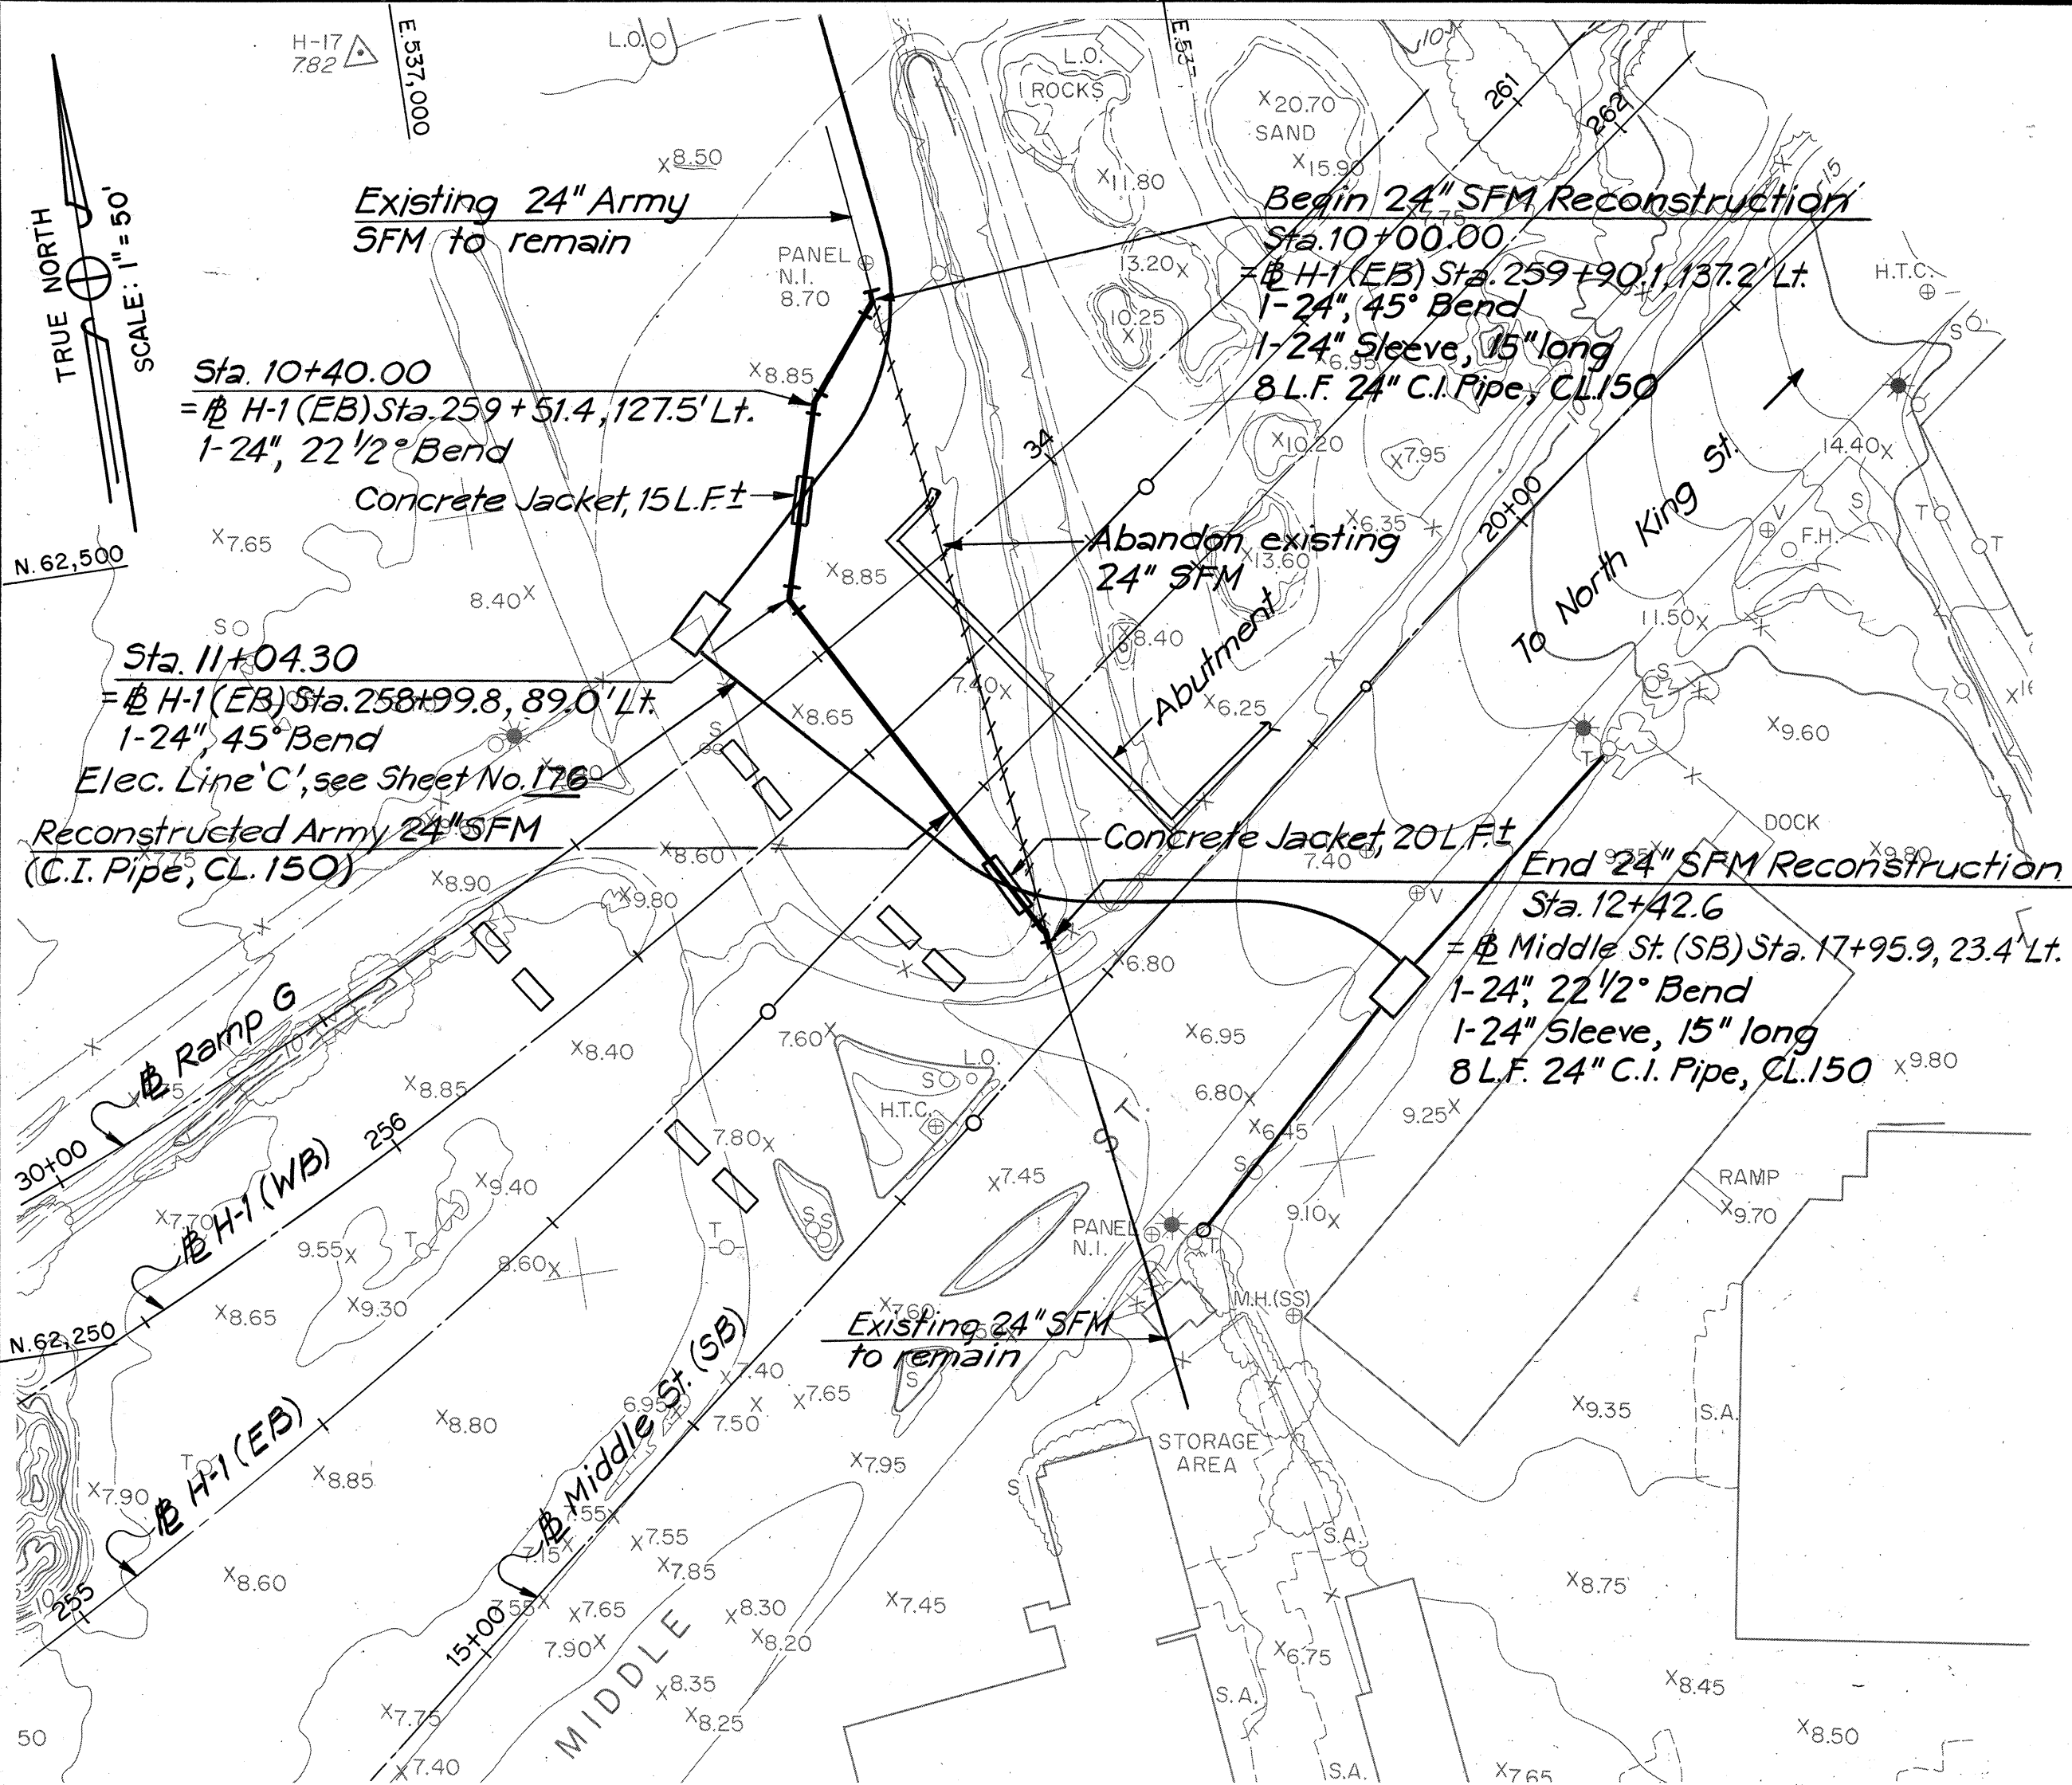

PLAN - 24" ARMY SEWER FORCE MAIN RECONSTRUCTION
Scale: 1" = 50'

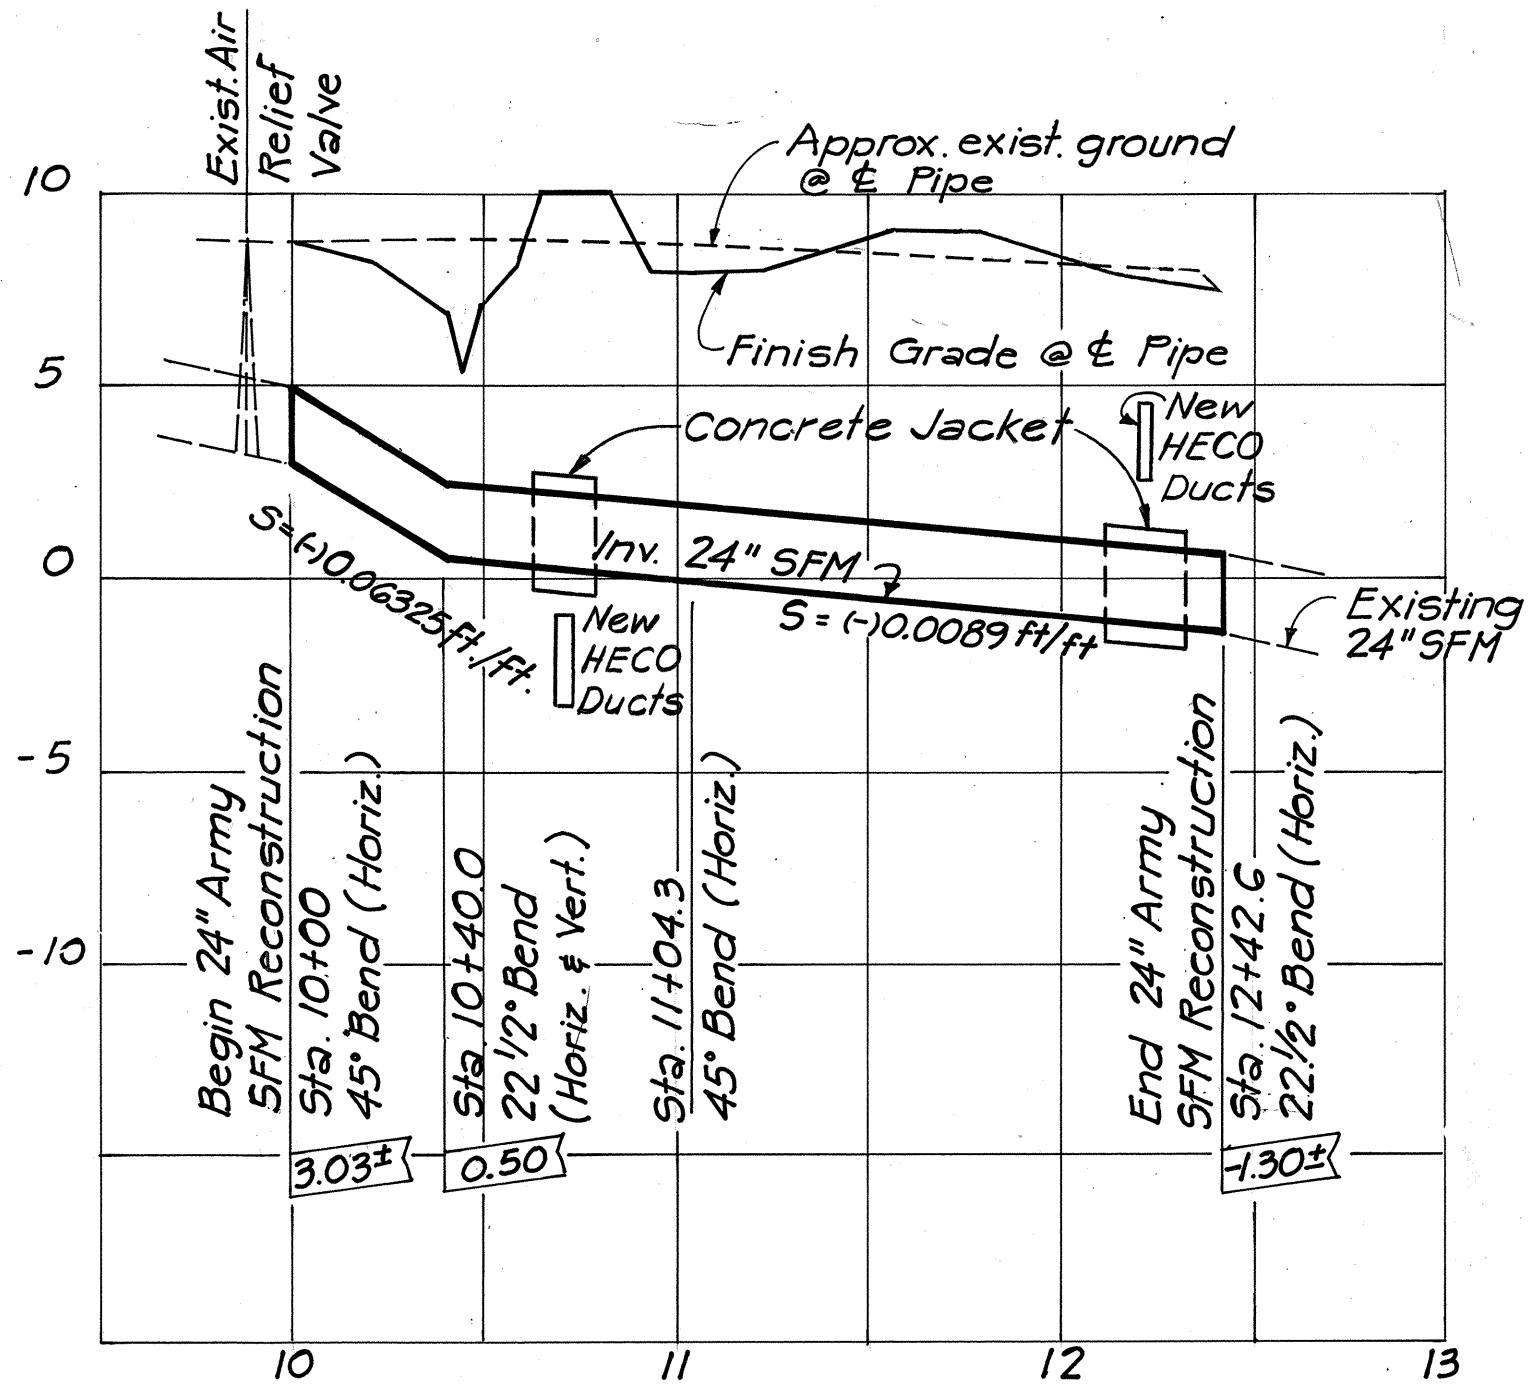


PROFILE - 24" SFM RECONSTRUCTION
Scale: Horiz. 1" = 50',
Vert. 1" = 5'

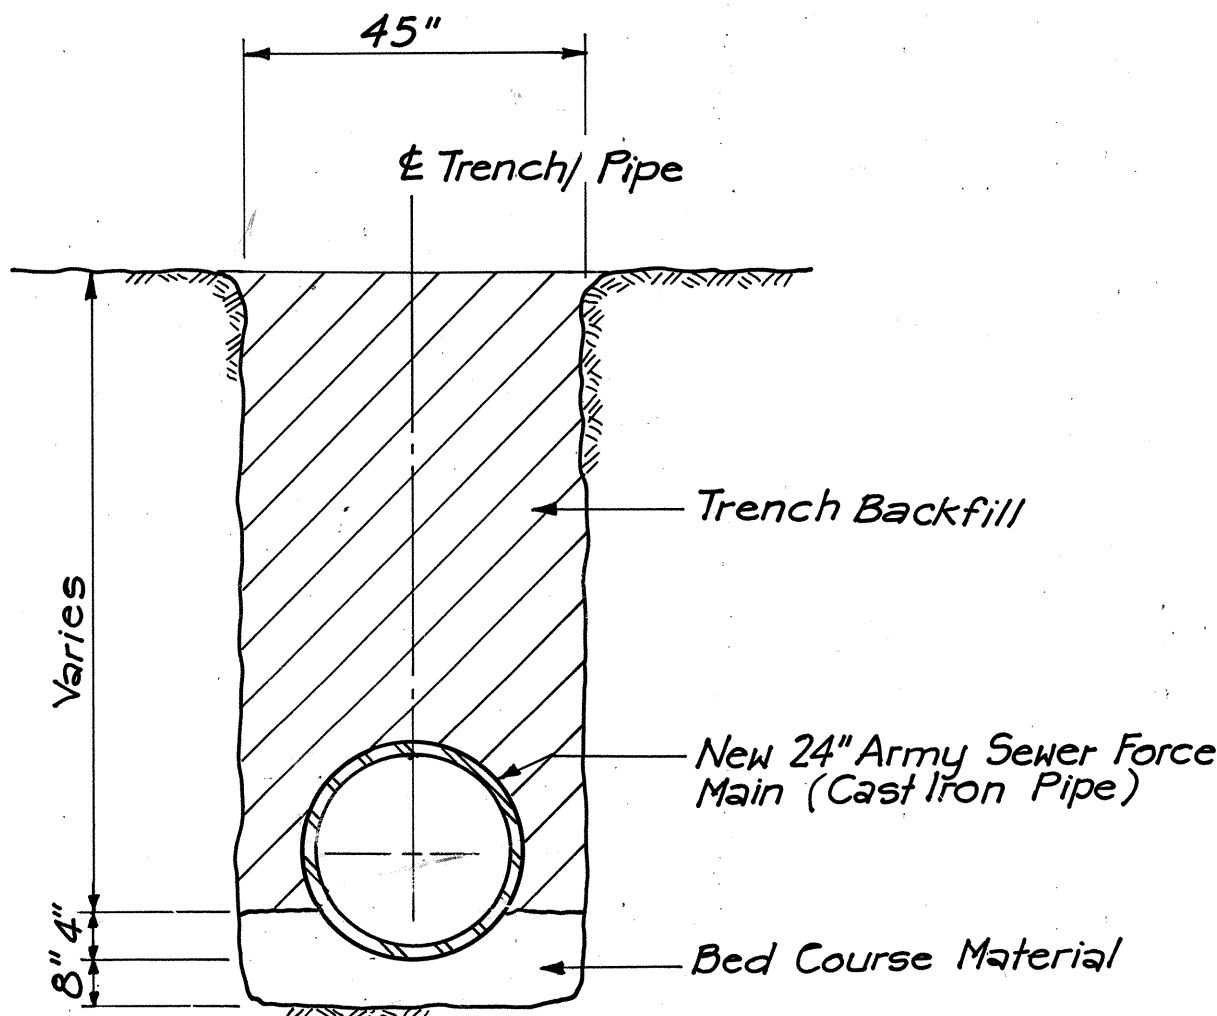

TYPICAL TRENCH DETAIL
N.T.S.

APPROVED:

James C. K. Pang 27 July 77
DIRECTOR OF FACILITIES ENGINEERING DATE

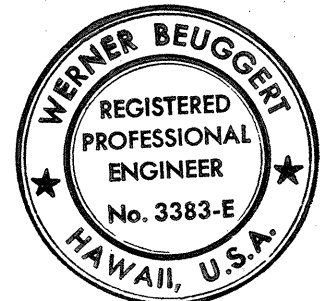

THIS WORK WAS PREPARED BY ME
OR UNDER MY SUPERVISION.
Werner Beugger


STATE OF HAWAII
DEPARTMENT OF TRANSPORTATION
HIGHWAYS DIVISION

**RECONSTRUCTION OF 24"
ARMY SEWER FORCE MAIN**


INTERSTATE ROUTE H-1
PROJECT NO. I-HI-1(131):17

SCALE: AS SHOWN DATE:
SHEET No. U-17 OF U-23 SHEETS


ORIGINAL PLAN	SURVEY PLOTTED BY _____ DATE _____	
	DRAWN BY _____	
NOTE BOOK	TRACED BY _____	
	DESIGNED BY _____	
	QUANTITIES BY _____	
	CHECKED BY _____	
No. _____		

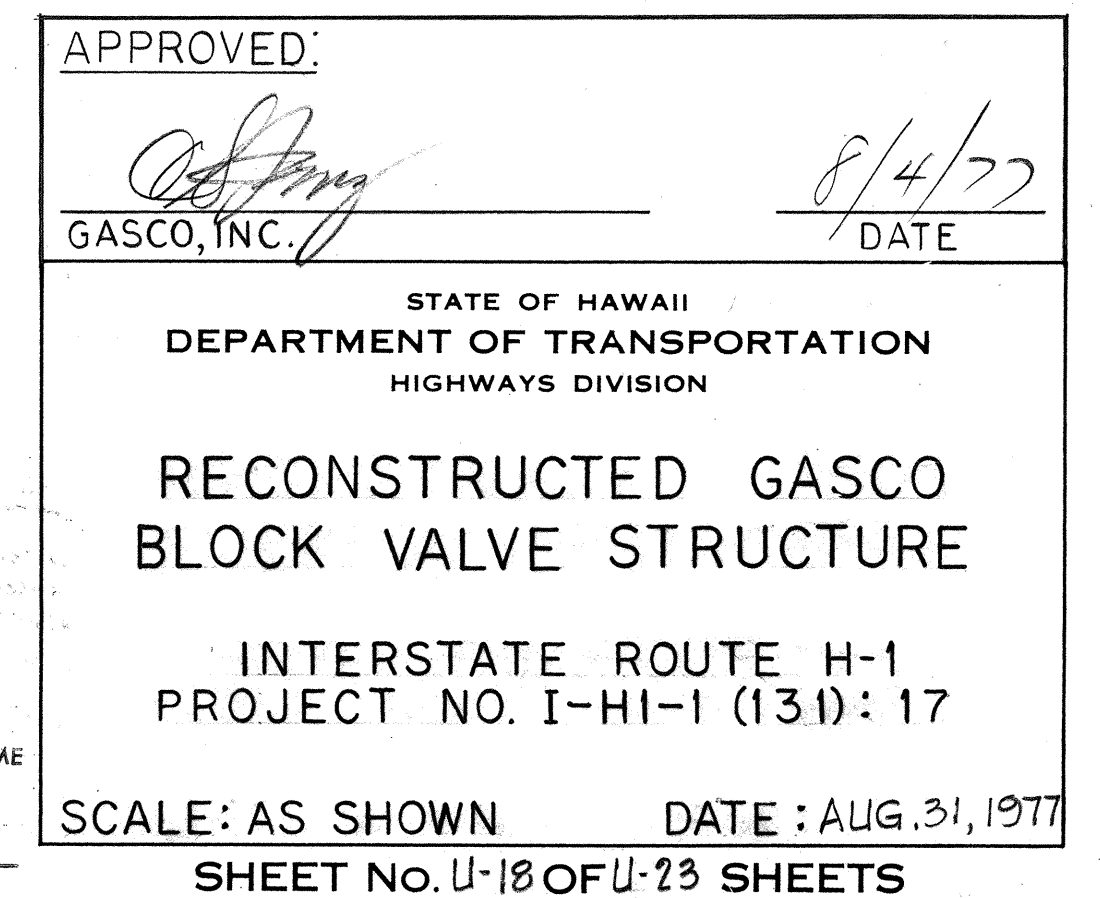

FED. ROAD DIST. NO.	STATE	FED. AID PROJ. NO.	FISCAL YEAR	SHEET NO.	TOTAL SHEETS
HAWAII	HAW.	I-HI-1(131)17	1977	191	394

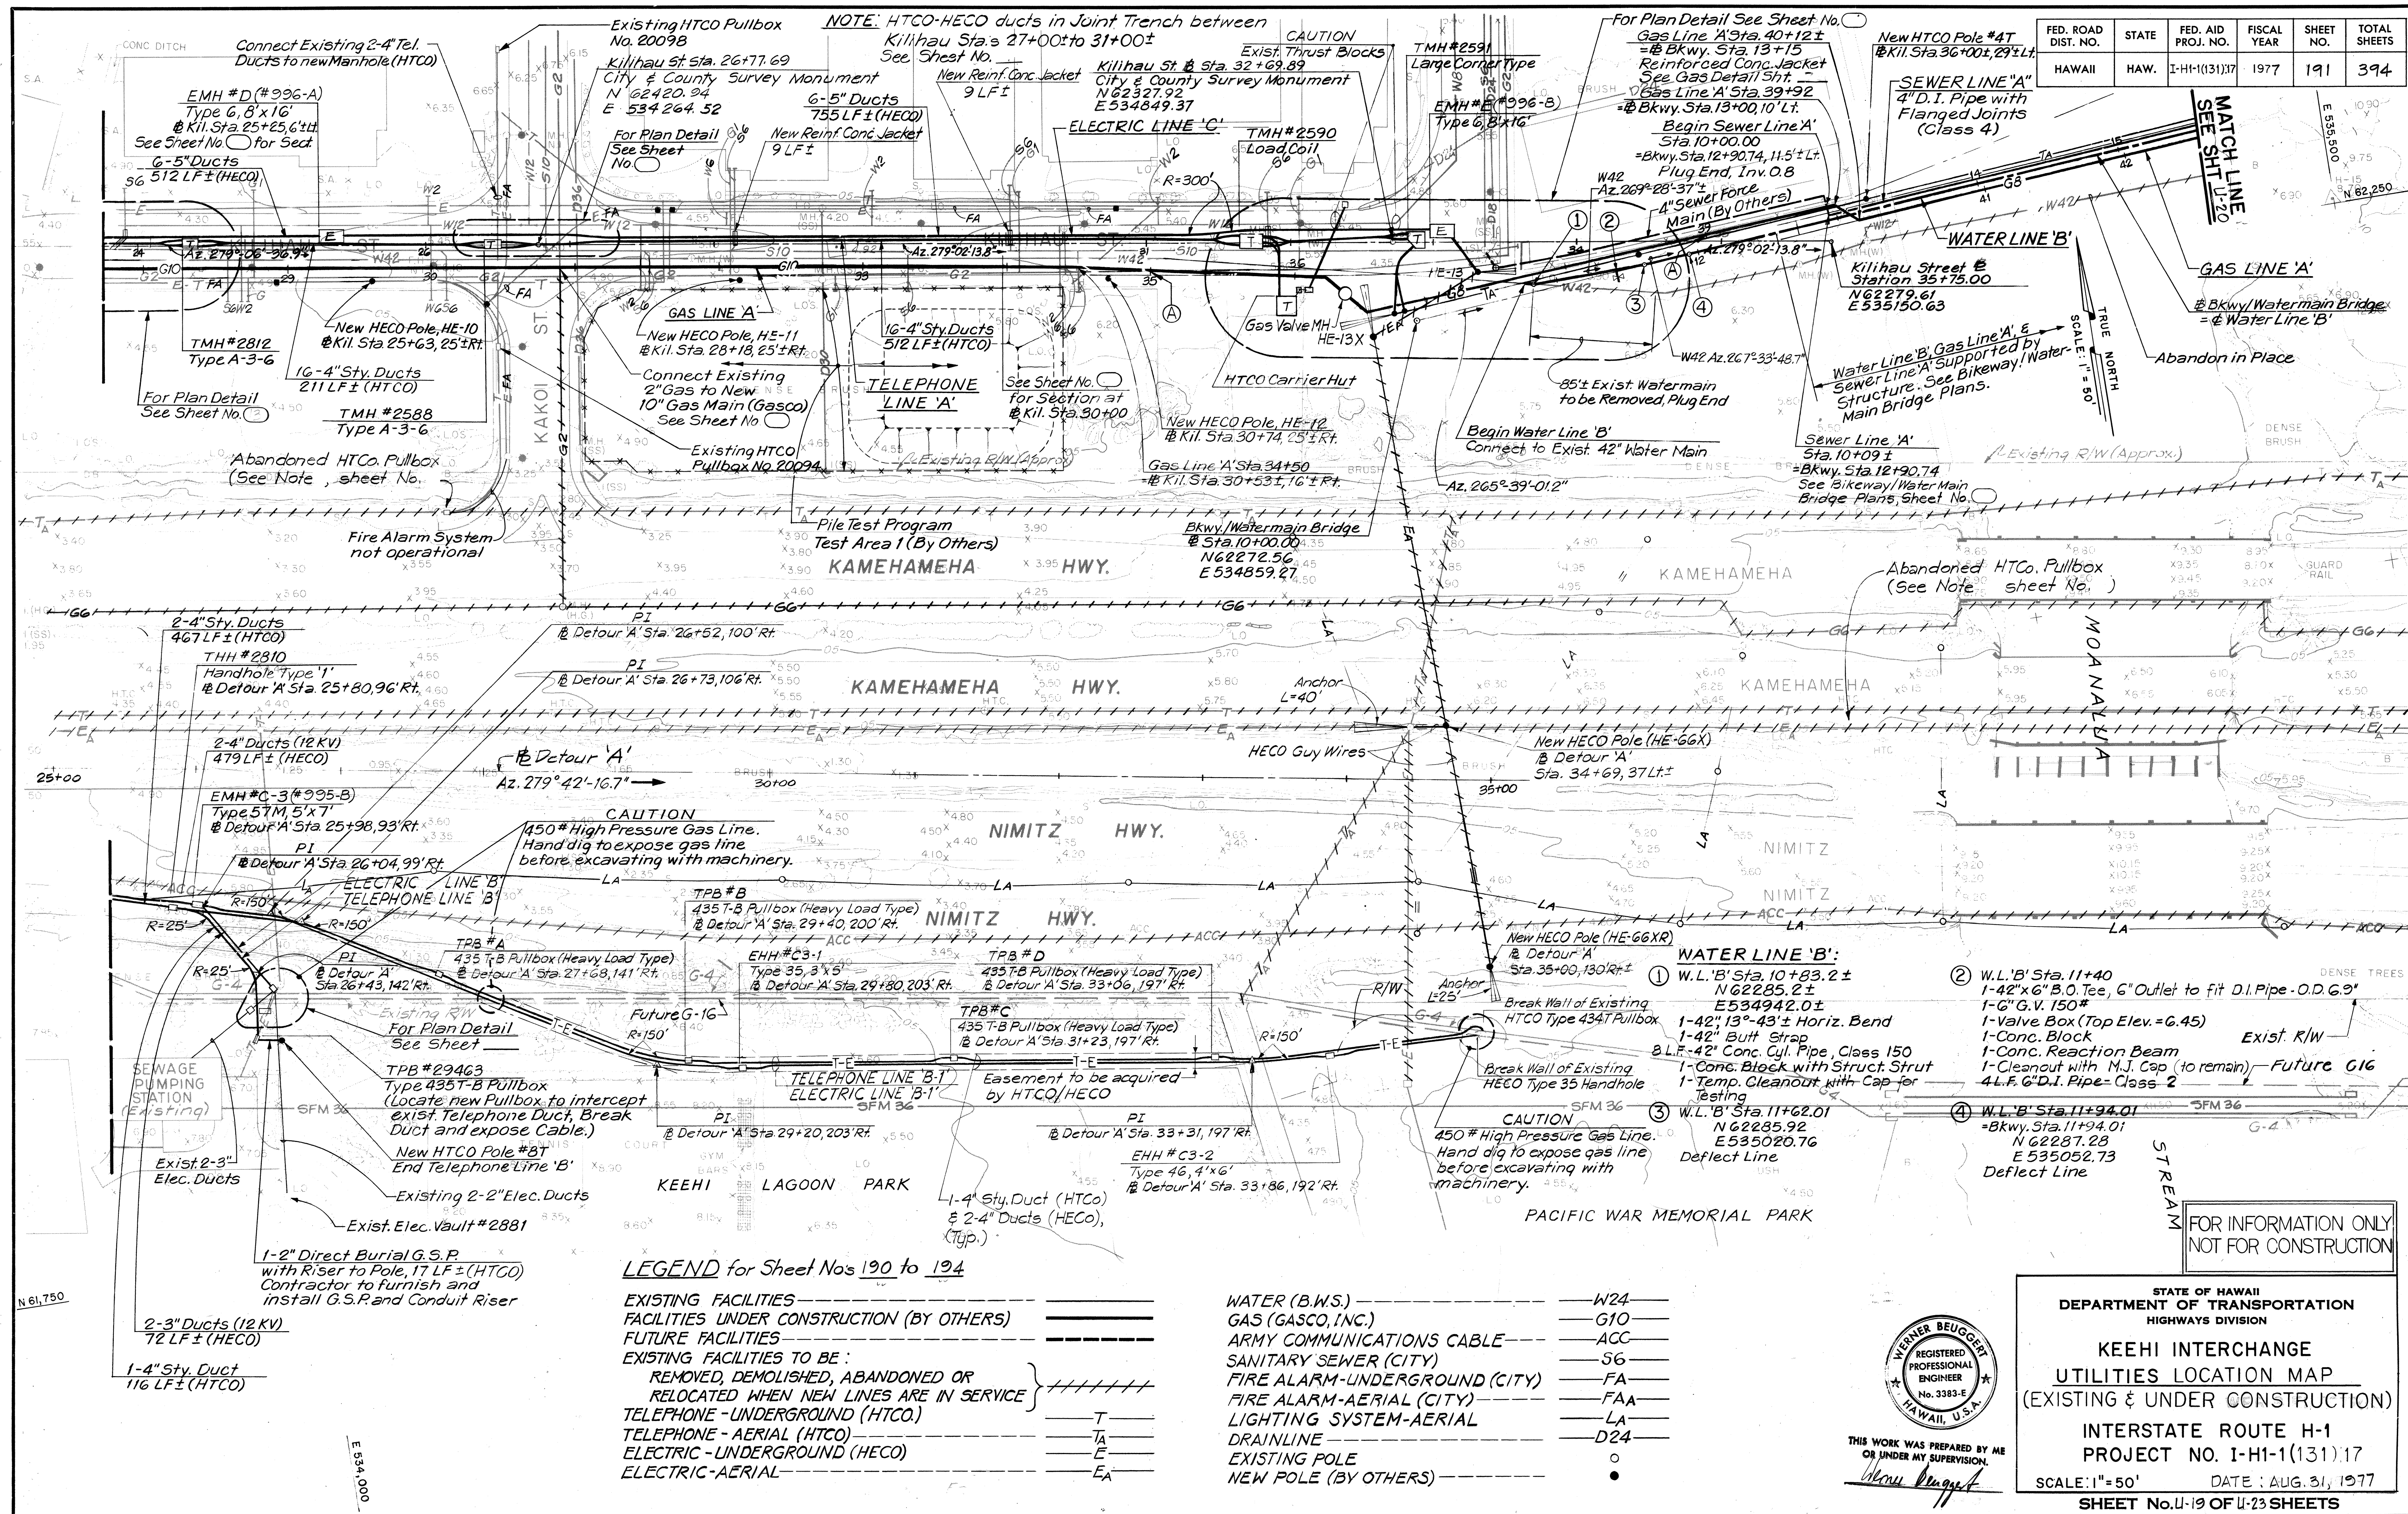

DATE: _____
SURVEY PLOTTED BY: _____
DRAWN BY: _____
DESIGNED BY: _____
CHECKED BY: _____
NO. _____

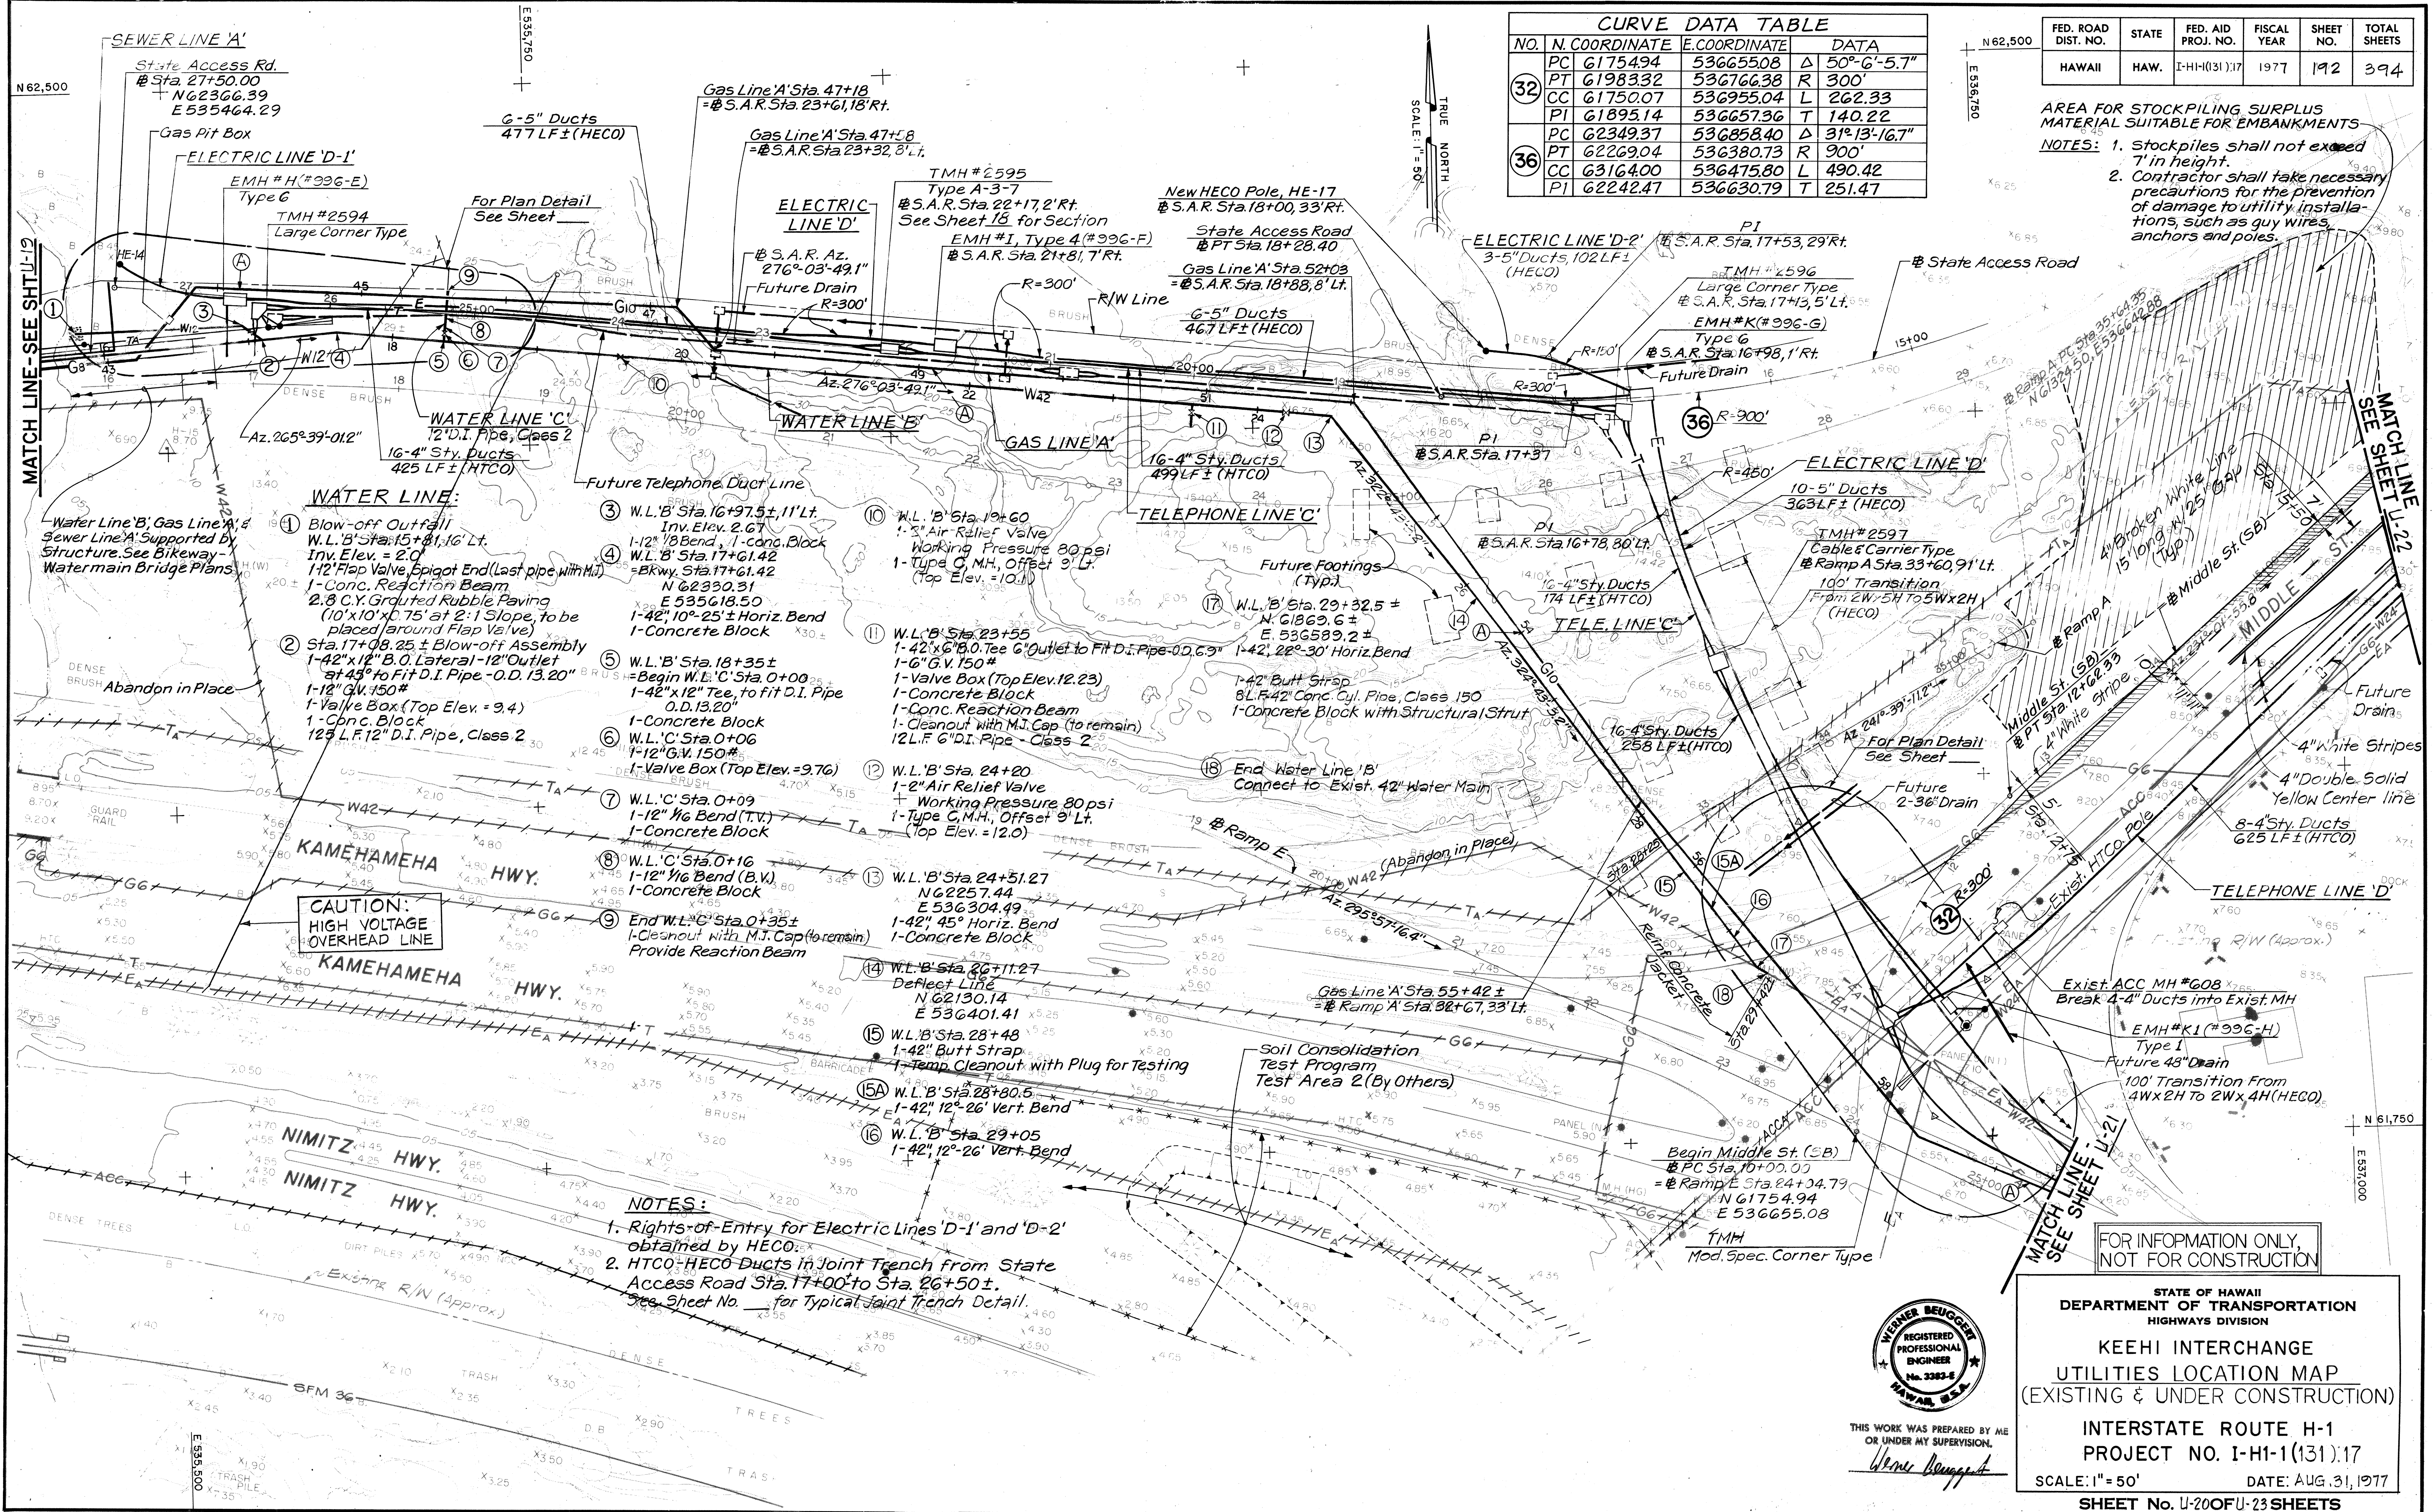

CURVE DATA TABLE				
NO.	N. COORDINATE	E. COORDINATE	DATA	
32	PC 61754.94	536655.08	Δ 50°-6'-5.7"	
	PT 61983.32	536766.38	R 300'	
	CC 61750.07	536955.04	L 262.33	
	PI 61895.14	536657.96	T 140.22	
36	PC 62349.37	536858.40	Δ 31°-13'-16.7"	
	PT 62269.04	536380.73	R 900'	
	CC 63164.00	536475.80	L 490.42	
	PI 62242.47	536630.79	T 251.47	

FED. ROAD DIST. NO.	STATE	FED. AID PROJ. NO.	FISCAL YEAR	SHEET NO.	TOTAL SHEETS
HAWAII	HAW.	I-HI-1(31)	1977	192	394

AREA FOR STOCKPILING SURPLUS MATERIAL SUITABLE FOR EMBANKMENTS
NOTES: 1. Stockpiles shall not exceed 7' in height.
2. Contractor shall take necessary precautions for the prevention of damage to utility installations, such as guy wires, anchors and poles.




STATE OF HAWAII
DEPARTMENT OF TRANSPORTATION
HIGHWAYS DIVISION

KEEHI INTERCHANGE
UTILITIES LOCATION MAP
(EXISTING & UNDER CONSTRUCTION)


INTERSTATE ROUTE H-1
PROJECT NO. I-HI-1(31).17
SCALE: 1" = 50' DATE: AUG. 31, 1977
SHEET No. U-20 OF U-23 SHEETS

ORIGINAL PLAN	SURVEY PLOTTED BY _____	DATE _____
NOTE BOOK	DRAWN BY _____	_____
	TRACED BY _____	_____
	DESIGNED BY _____	_____
	QUANTITIES BY _____	_____
No. _____	CHECKED BY _____	_____

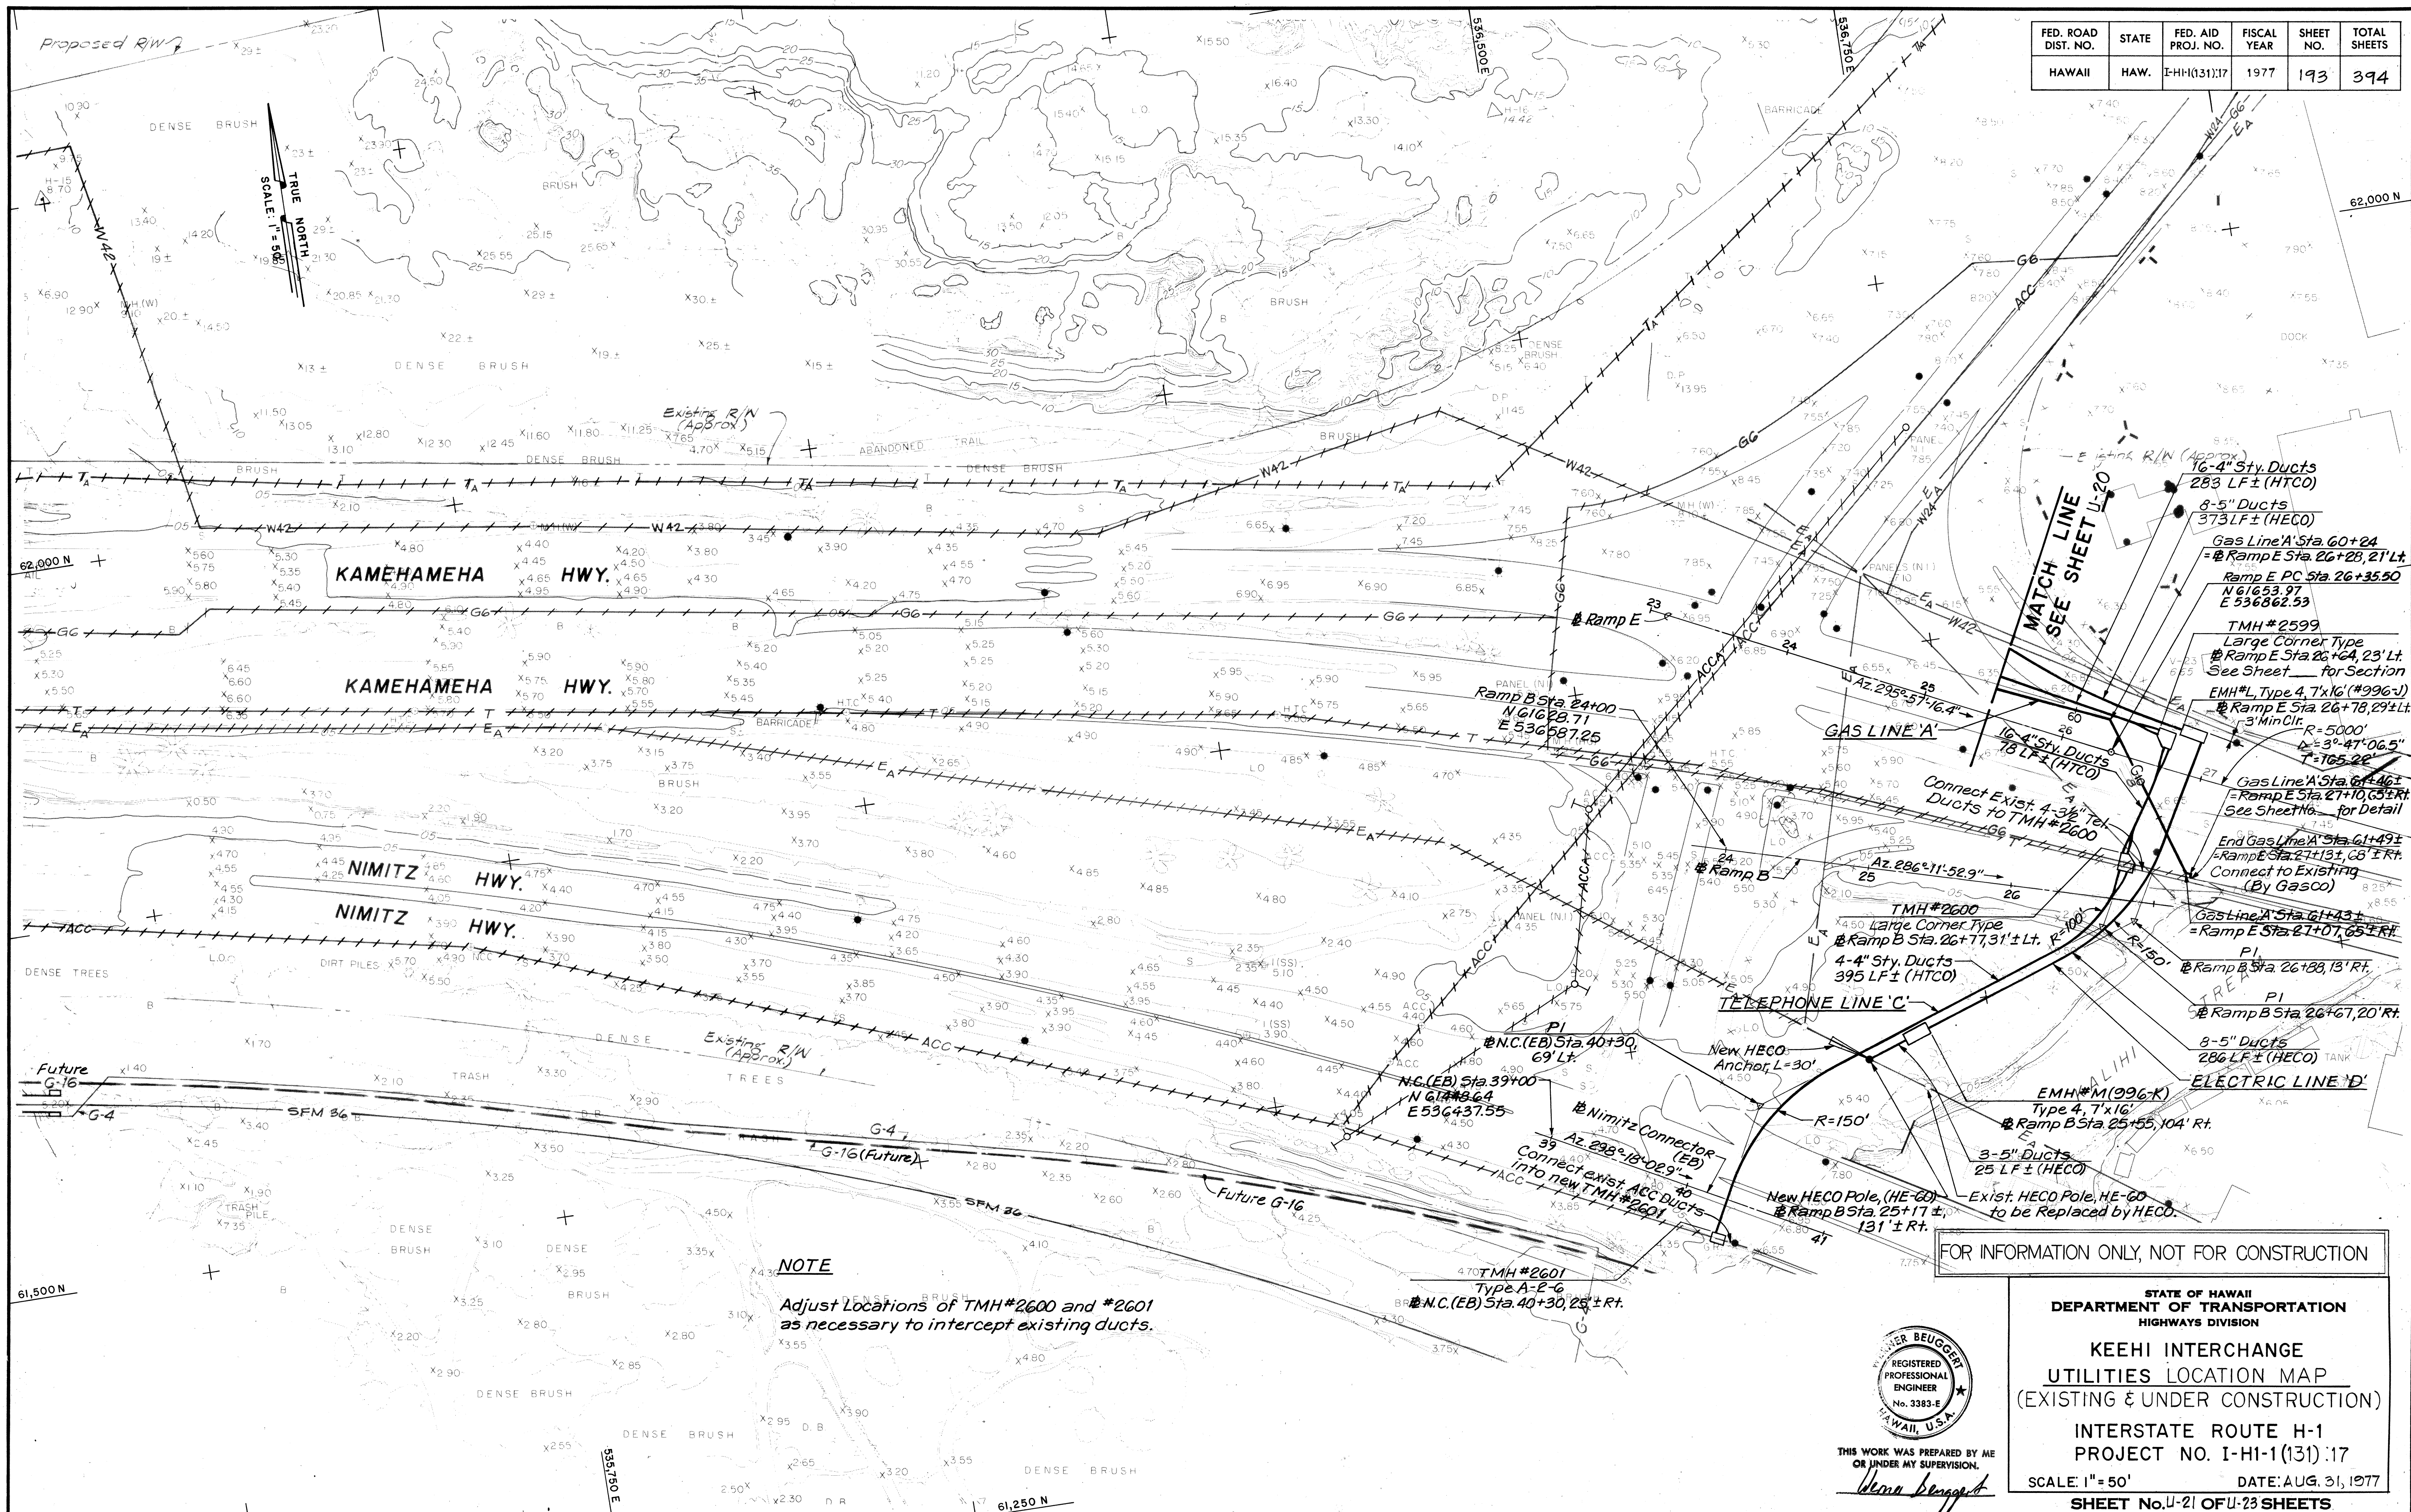


FED. ROAD DIST. NO.	STATE	FED. AID PROJ. NO.	FISCAL YEAR	SHEET NO.	TOTAL SHEETS
HAWAII	HAW.	I-H-1(131)17	1977	124	394


CURVE DATA TABLE				
NO.	N.COORDINATE	E.COORDINATE	DATA	
33	PC 6240082	537282.54	Δ 5°-6'-2.2"	
	PT 6255931	537497.38	R 3000	
	CC 6006832	539169.19	L 267.07	
	PI 6248485	537386.43	T 133.62	

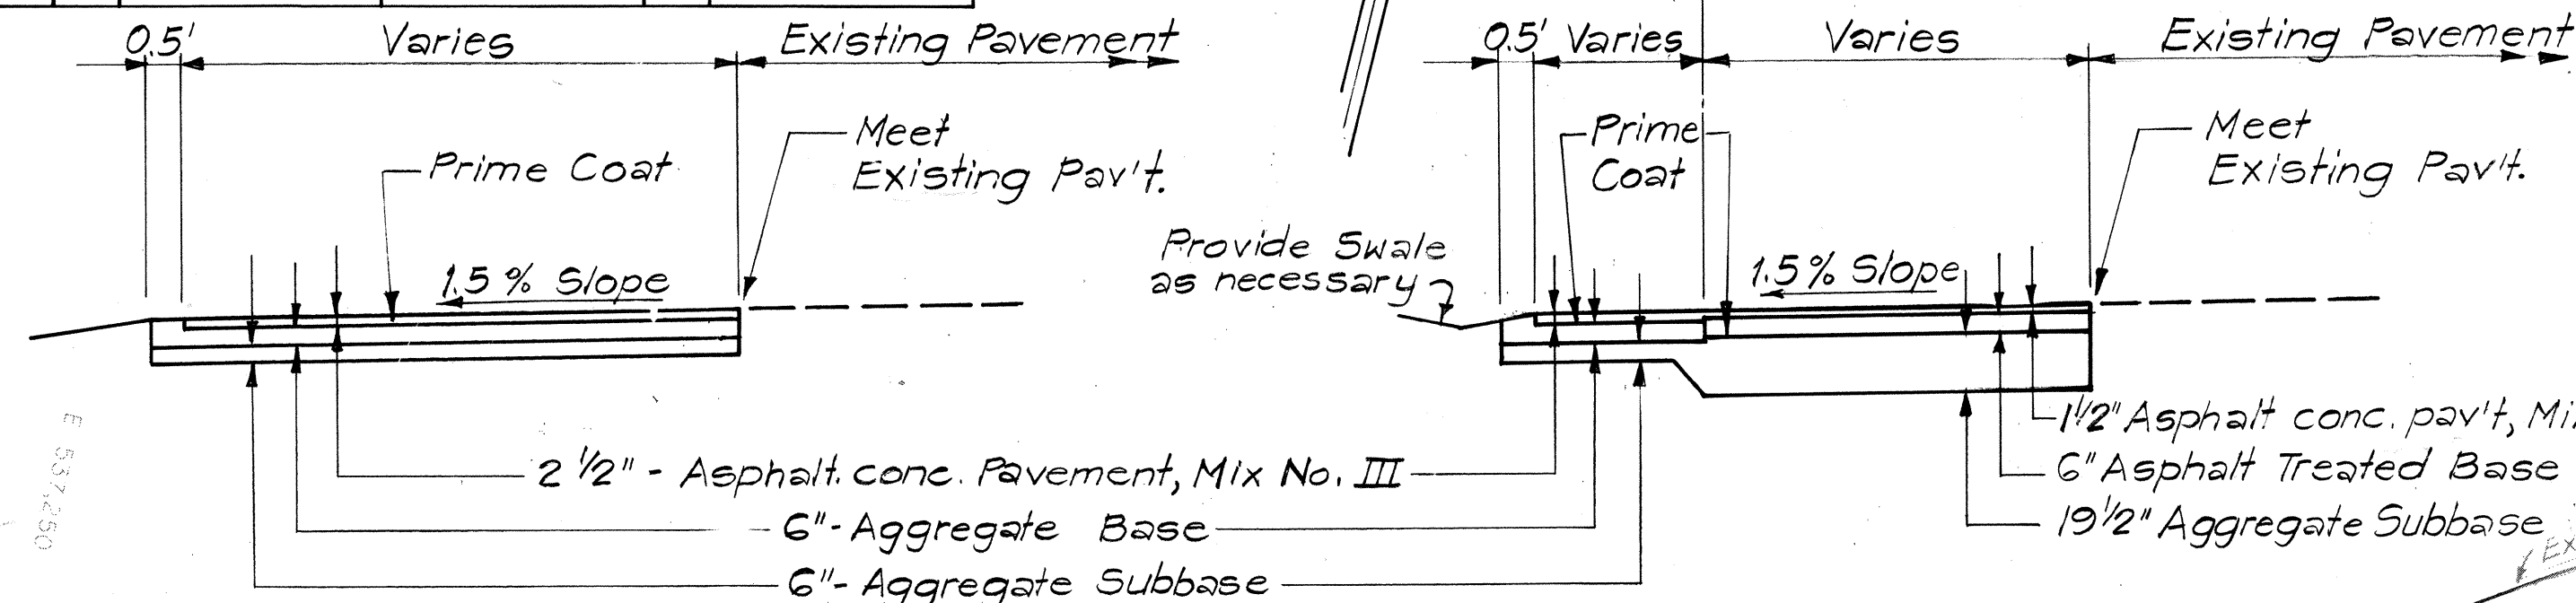

SOUTH BOUND STA. 12+00 ± TO STA. 28+00 ± SOUTH BOUND STA. 28+00 ± TO STA. 32+40 ±
TYPICAL SECTIONS OF MIDDLE ST. DETOUR
N.T.S.

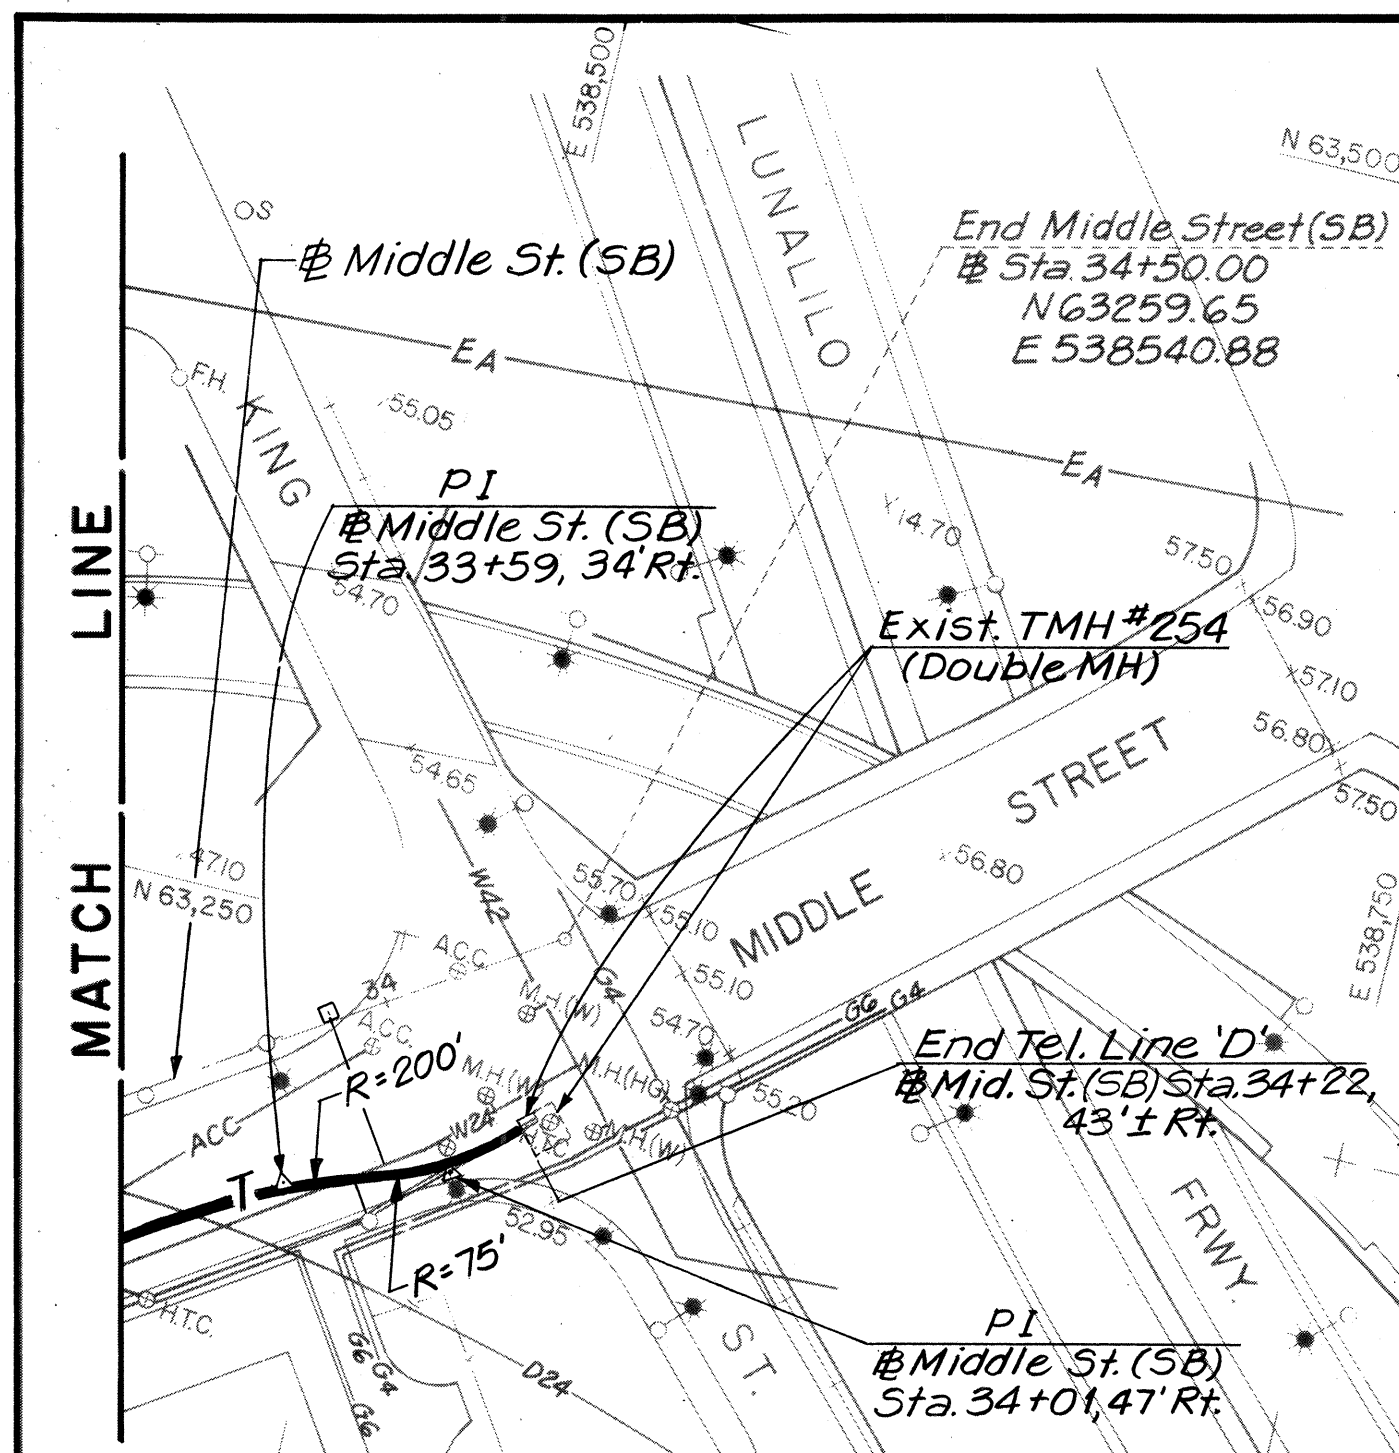

INSERT

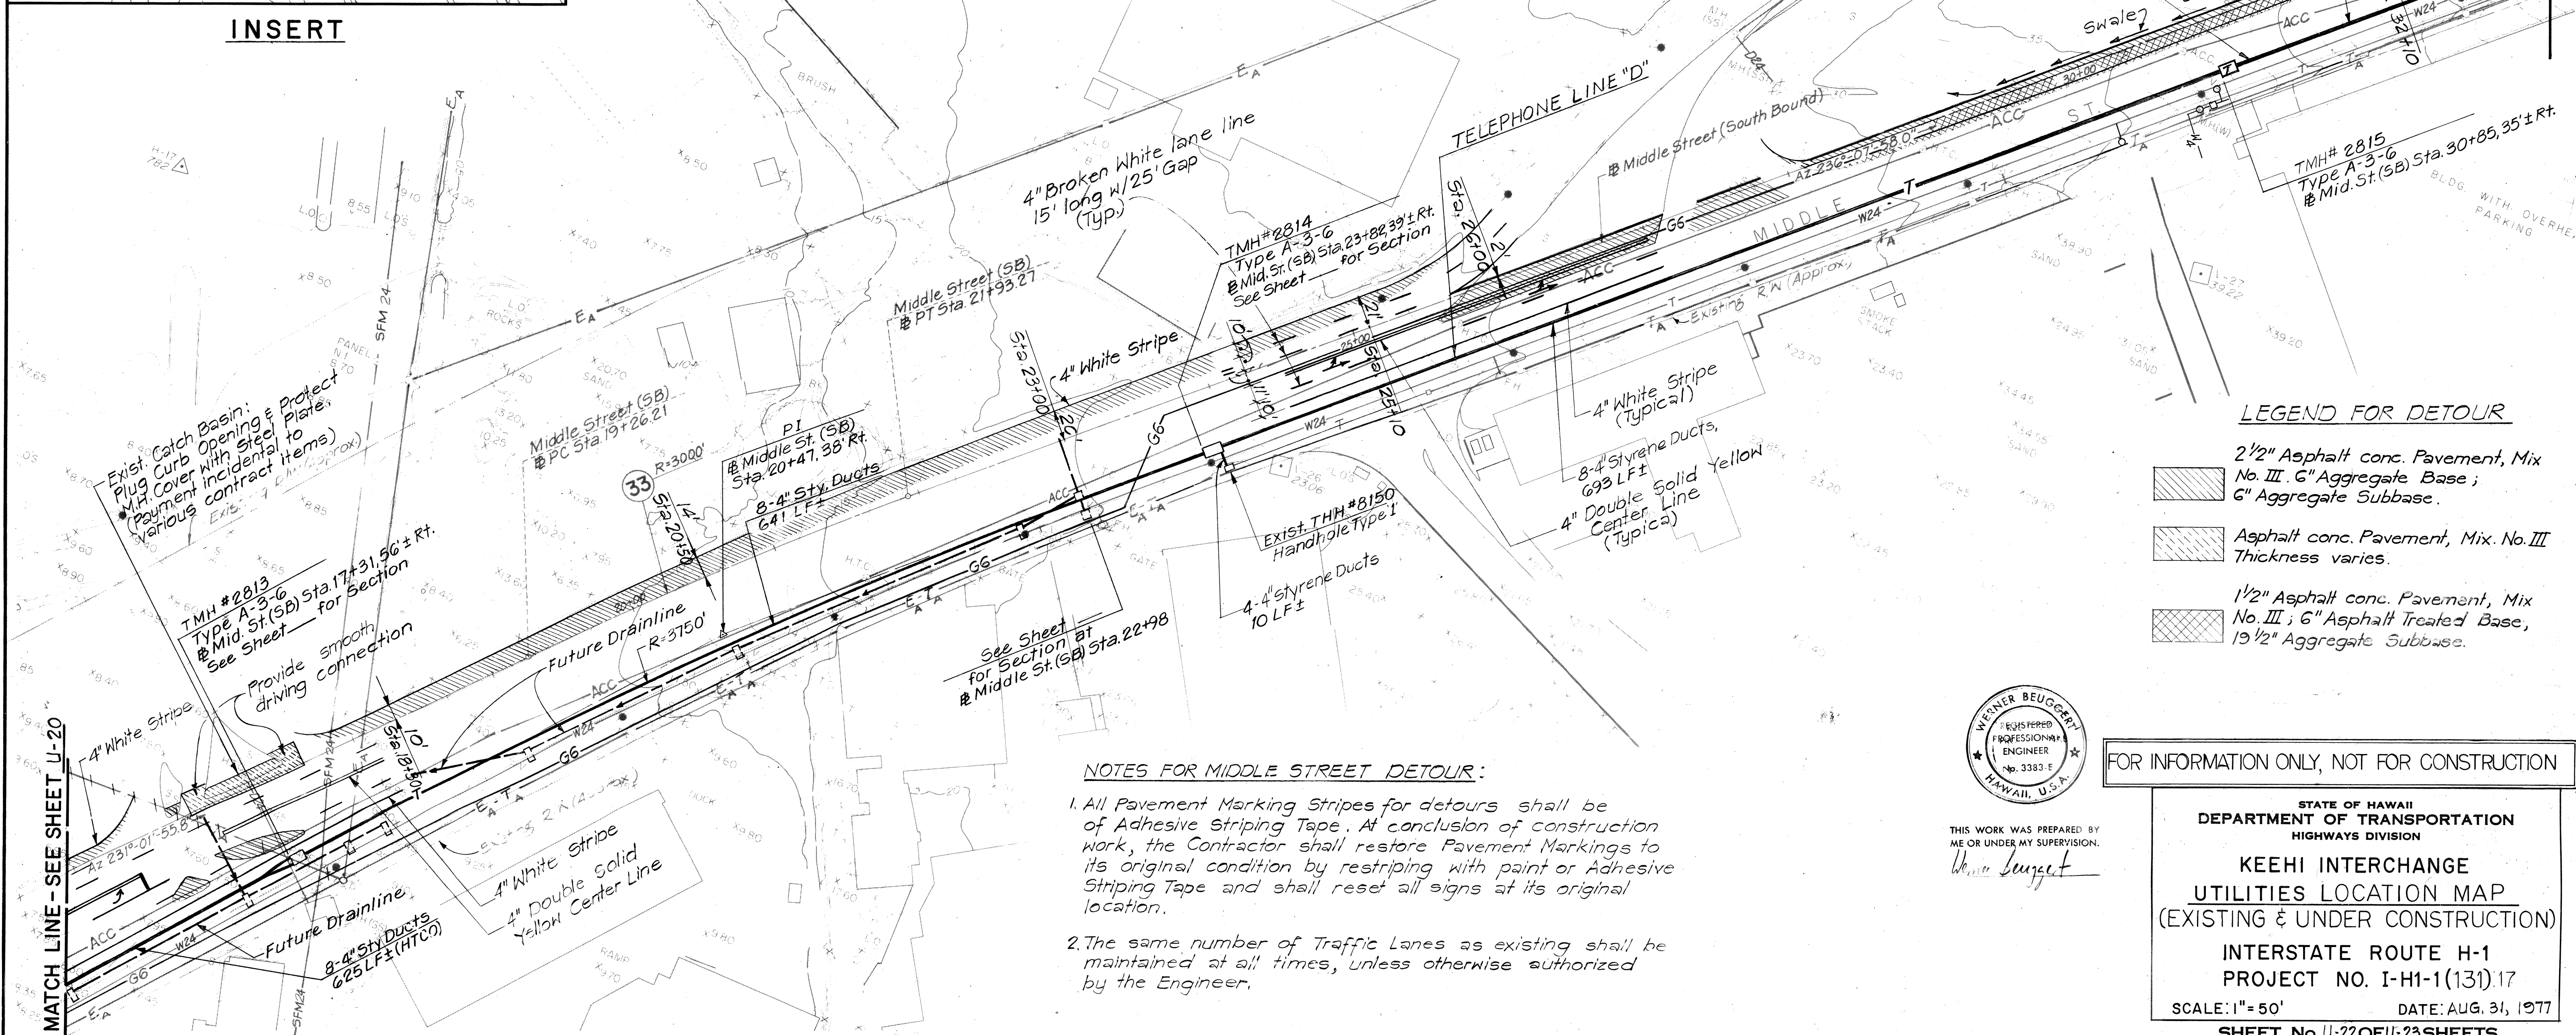


LEGEND FOR DETOUR

- 2 1/2" Asphalt conc. Pavement, Mix No. III; 6" Aggregate Base; 6" Aggregate Subbase.
- Asphalt conc. Pavement, Mix. No. III Thickness varies.
- 1 1/2" Asphalt conc. Pavement, Mix No. III; 6" Asphalt Treated Base, 19 1/2" Aggregate Subbase.

NOTES FOR MIDDLE STREET DETOUR:

- All Pavement Marking Stripes for detours shall be of Adhesive Striping Tape. At conclusion of construction work, the Contractor shall restore Pavement Markings to its original condition by restriping with paint or Adhesive Striping Tape and shall reset all signs at its original location.
- The same number of Traffic Lanes as existing shall be maintained at all times, unless otherwise authorized by the Engineer.

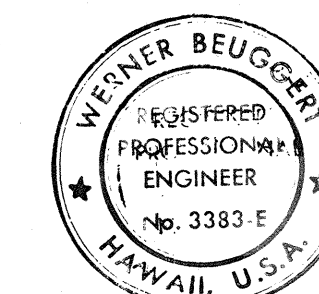

THIS WORK WAS PREPARED BY ME OR UNDER MY SUPERVISION.

Werner Beugert

FOR INFORMATION ONLY, NOT FOR CONSTRUCTION

STATE OF HAWAII
DEPARTMENT OF TRANSPORTATION
HIGHWAYS DIVISION
KEEHI INTERCHANGE
UTILITIES LOCATION MAP
(EXISTING & UNDER CONSTRUCTION)
INTERSTATE ROUTE H-1
PROJECT NO. I-H-1(131)17
SCALE: 1" = 50' DATE: AUG. 31, 1977
SHEET No. U-22 OF U-23 SHEETS

FED. ROAD DIST. NO.	STATE	FED. AID PROJ. NO.	FISCAL YEAR	SHEET NO.	TOTAL SHEETS
HAWAII	HAW.	FHH(131):17	1977	195	394

ORIGINAL PLAN	DATE
SURVEY NOTED BY	
DRAWN BY	
DESIGNED BY	
CHECKED BY	



THIS WORK WAS PREPARED BY ME
OR UNDER MY SUPERVISION.

Peter Beugger

STATE OF HAWAII
DEPARTMENT OF TRANSPORTATION
HIGHWAYS DIVISION

**UTILITIES PLAN
EXISTING**

INTERSTATE ROUTE H-1
PROJECT NO. I-H-1(131):17

SCALE: 1" = 50' DATE: AUG. 31, 1977

SHEET No. U-23 OF U-23 SHEETS