	INDEX TO DRAWINGS
SHEET NO.	DESCRIPTION
	TITLE SHEET
2	GENERAL PLAN
3	TYPICAL SECTIONS
4	ALIGNMENT PLAN, PROFILE & S.E. DIAGRAM
5	RAMP TERMINAL DETAILS
6	GRADING, DRAINAGE & CONSTRUCTION PLAN
7	FENCE LOCATION PLAN
8	DRAINAGE PROFILES & SUMMARY
9-14	DRAINAGE DETAILS
15-22	CONSTRUCTION DETAILS
23-25	RETAINING WALL DETAILS
26	SIGNING AND PAVEMENT MARKING PLAN
27, 28	GUIDE SIGN LOCATION PLAN
29-42	SIGN AND PAVEMENT MARKING DETAILS
43-45	ELECTRICAL PLAN & DETAILS
46,47	PLANTING PLAN & DETAILS
48,49	IRRIGATION PLAN & DETAILS
5 <b>0</b> -52	CROSS SECTIONS

TOTAL SHEET COUNT AFTER "AS-BUILT"

POSTINGS : 56 SHEETS.

STATE OF HAWAII

DEPARTMENT OF TRANSPORTATION LAND TRANSPORTATION FACILITIES DIVISION HONOLULU, HAWAII


"AS - BUILT" PLANS FOR CONSTRUCTION OF A PORTION OF


## INTERSTATE ROUTE H-I

HALAWA INTERCHANGE EXIT RAMP TO AIEA

ARE SHEET NOS. (a) C.O. 21 S-1, (b) ADD34 S-1, CO30S-1
FEDERAL AID INTERSTATE PROJECT NO. I-HI-I(144): 13

DISTRICT OF EWA ISLAND OF OAHU

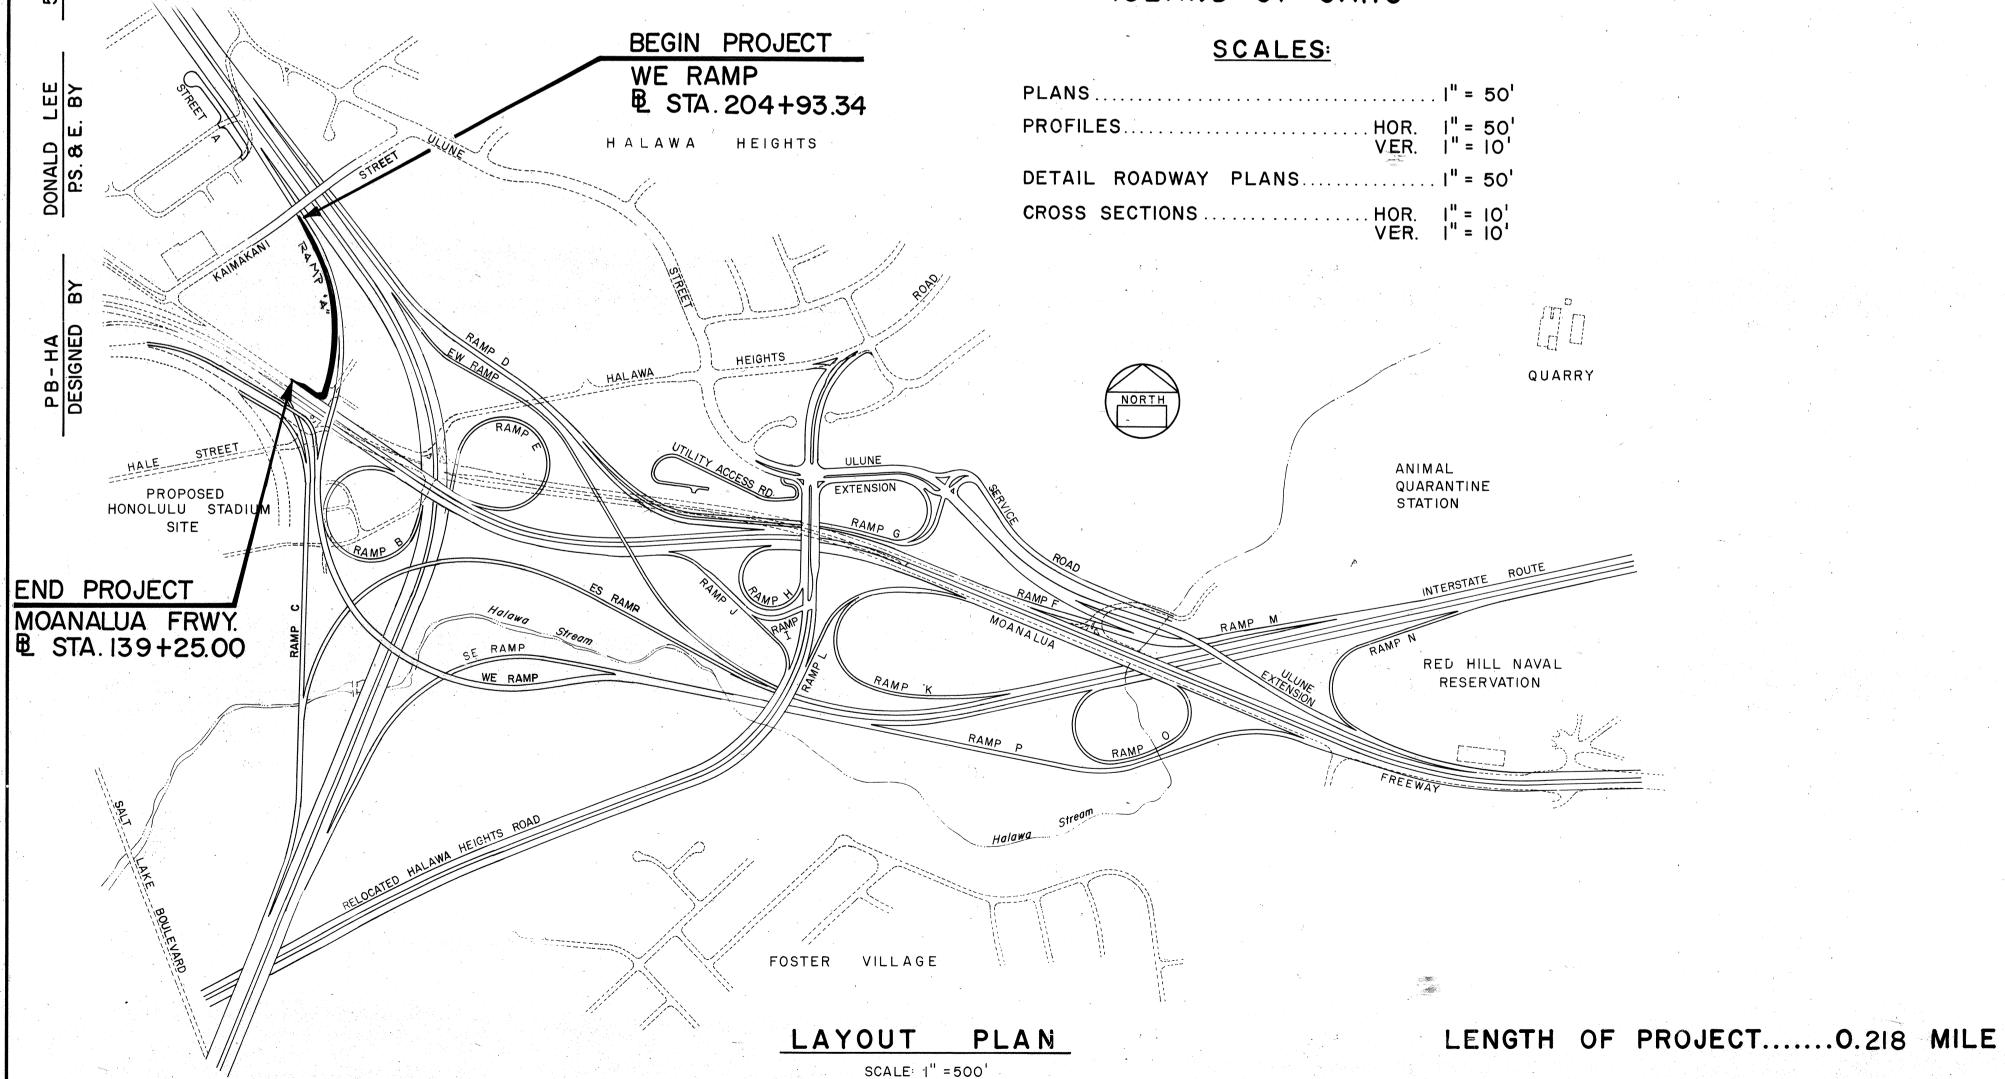

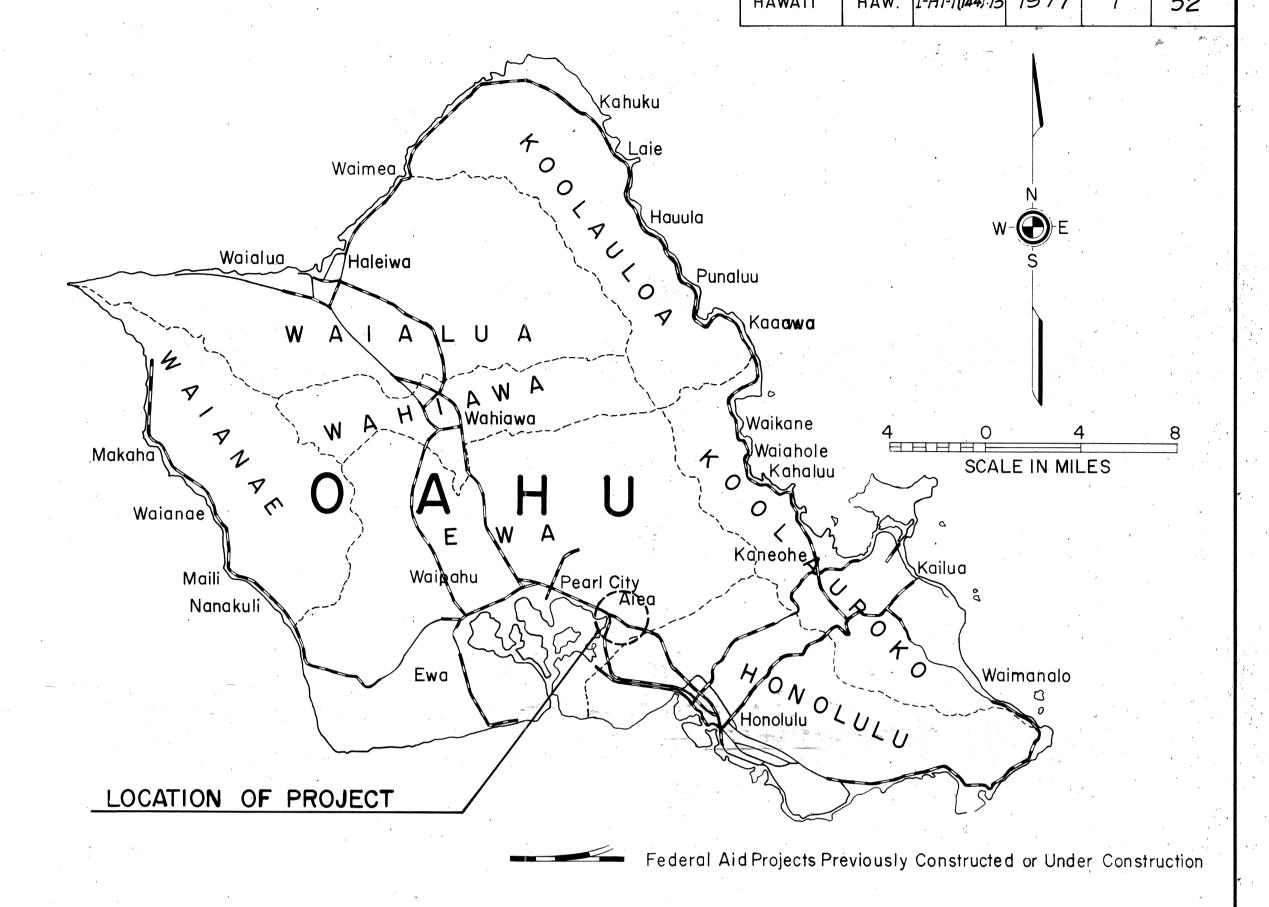

## DESIGN CLASSIFICATION

DESIGN ADT (1997)..... 2,808 D..... (NOT APPLICABLE) T...... 5% V..... 25 MPH

> ALL CHANGES MADE DURING CONSTRUCTION HAVE BEEN INCORPORATED ON THESE PLANS IN RED EXCEPT CHANGES IN THE ORIGINAL THEORETICAL QUANTITIES. FOR ACTUAL QUANTITIES, REFER TO PROJECT LEDGER AND/OR COMPUTATION BOOK.

30 Mar. 1981

STATE FED. AID FISCAL SHEET PROJ. NO. YEAR NO.

DEPARTMENT OF TRANSPORTATION FEDERAL HIGHWAY ADMINISTRATION 9.28.77

DEPARTMENT OF TRANSPORTATION STATE OF HAWAII APPROVED: