	INDEX TO DRAWINGS
SHEET NO.	DESCRIPTION
1	TITLE SHEET
2	TYPICAL SECTIONS
3	GENERAL NOTES, GUARD RAIL SCHEDULES AND DETAILS
4 - 5	ROADWAY PLANS
6-12	MISCELLANEOUS & STANDARD GUARD RAIL DETAILS
l3-25	SIGNING, PAVEMENT MARKING AND LIGHTING PLANS AND DETAILS
, A	
f :	



STATE OF HAWAII



DEPARTMENT OF TRANSPORTATION HIGHWAYS DIVISION

"AS-BUILT"


PLANS FOR

## INTERSTATE ROUTE H-I


RESURFACING OF PALAILAI AND KUNIA INTERCHANGES

FEDERAL AID INTERSTATE PROJECT NO. I-IR-HI-I(159)

DISTRICT OF EWA ISLAND OF OAHU

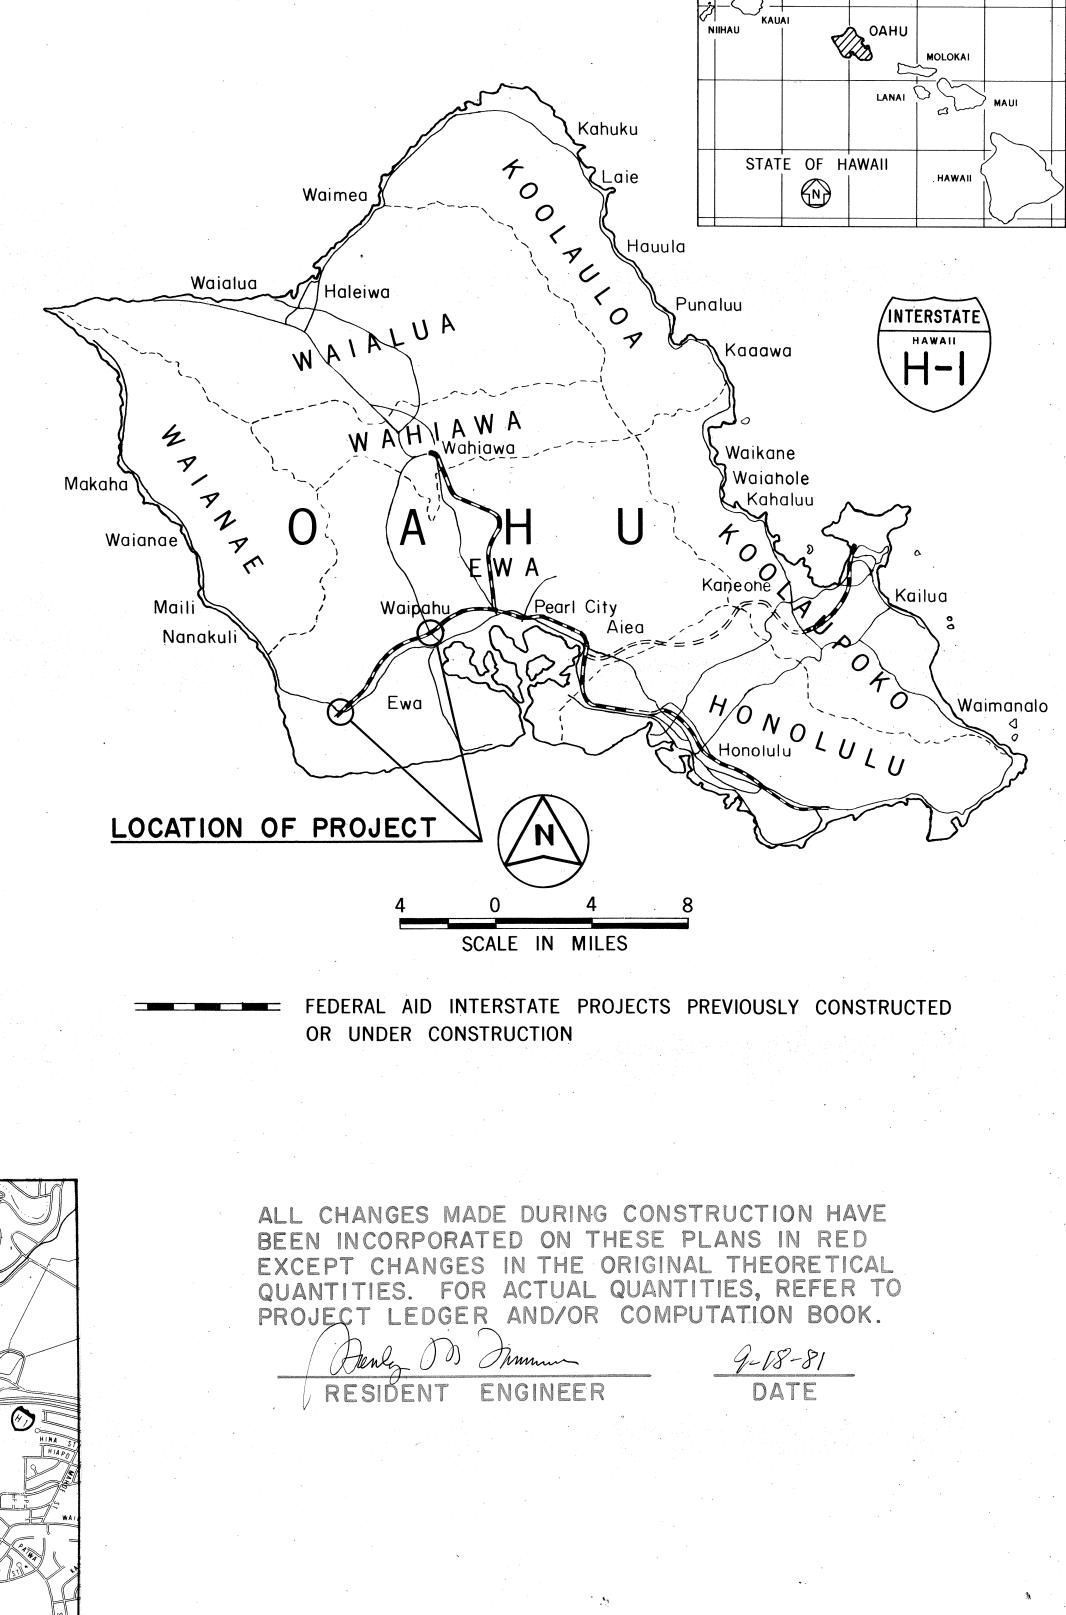

STATE

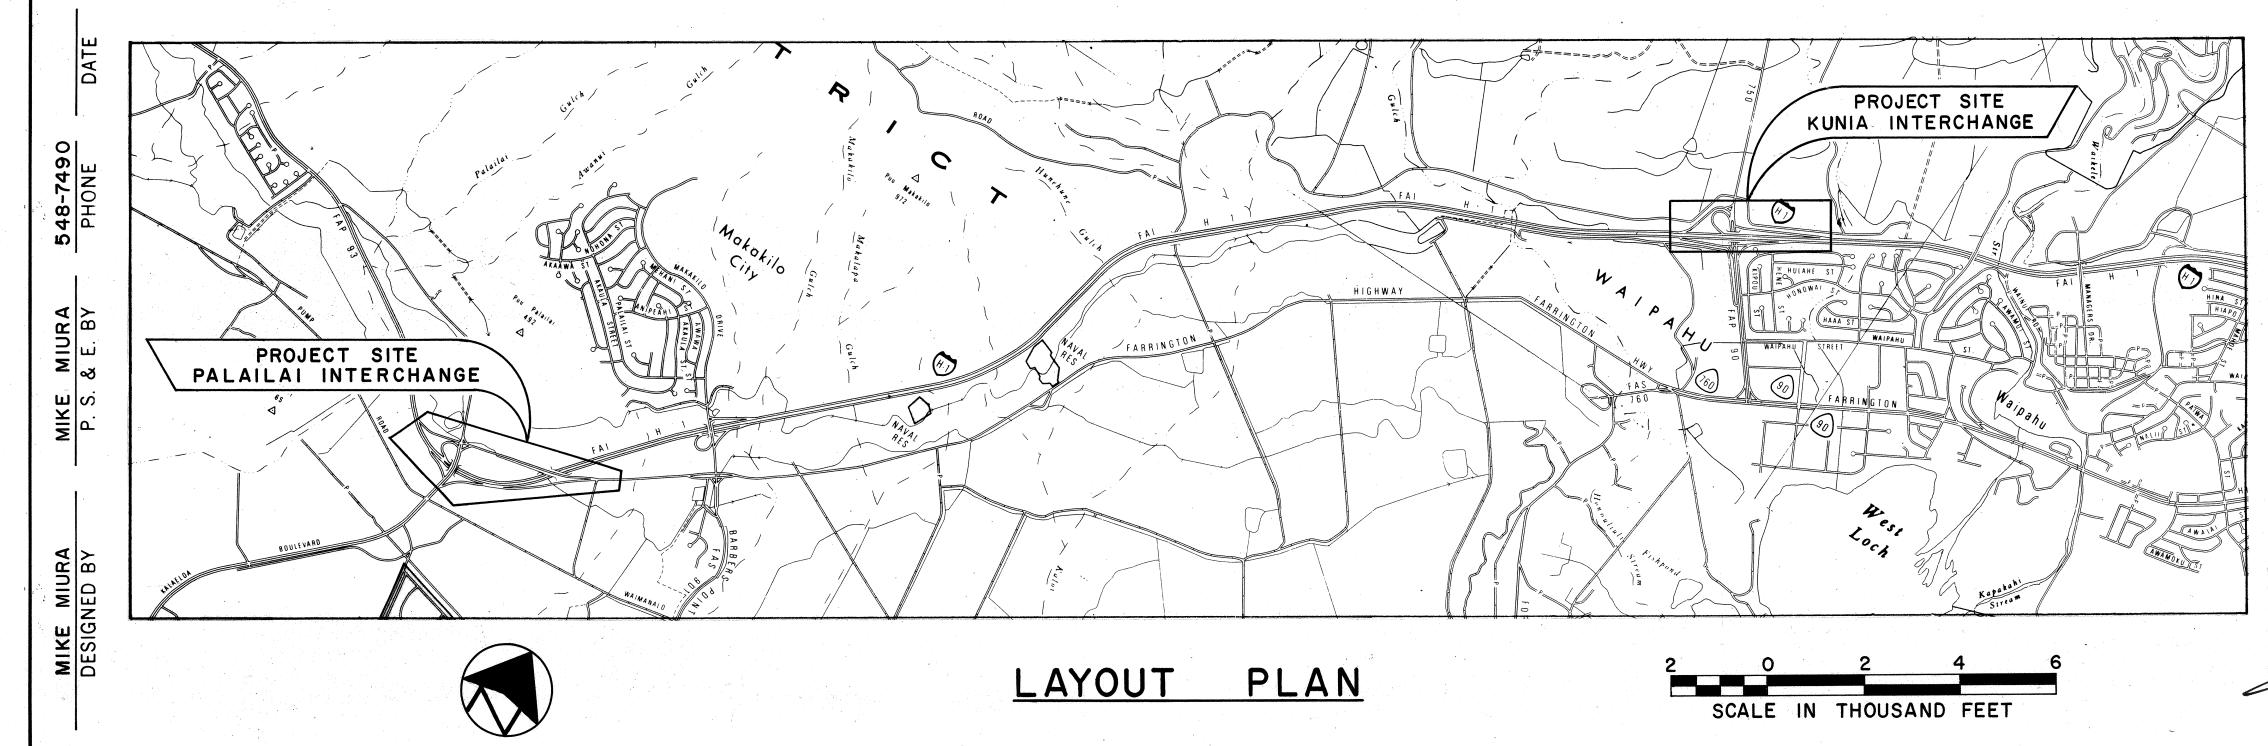

FEDERAL HIGHWAY ADMINISTRATION

APPROVED:

5.23.80

DIVISION ADMINISTRATOR

DATE

DEPARTMENT OF TRANSPORTATION

DEPARTMENT OF TRANSPORTATION
STATE OF HAWAII

APPROVED:

James K Carras 5/1/80
DIR. OF TRANSPORTATION DATE