* .	
	INDEX TO DRAWINGS
SHEET NO.	DESCRIPTION
	TITLE SHEET
2	TYPICAL SECTION & GENERAL NOTES
3	PLAN
4	SPRINKLER PLAN
5	PAVEMENT MARKING & STRIPING
6	UTILITY PLAN
7	CROSS SECTIONS
8 – 20	MISCELLANEOUS & STANDARD DETAILS

R. SIAROT P. S. & E. BY





STATE OF HAWAII

DEPARTMENT OF TRANSPORTATION HIGHWAYS DIVISION

"AS BUILT" PLANS FOR CONSTRUCTION INTERSTATE ROUTE H-1 HALAWA INTERCHANGE IMPROVEMENTS TO RAMP N F.A.I. PROJECT NO IR-HI-I(176)

> DISTRICT OF EWA ISLAND OF OAHU

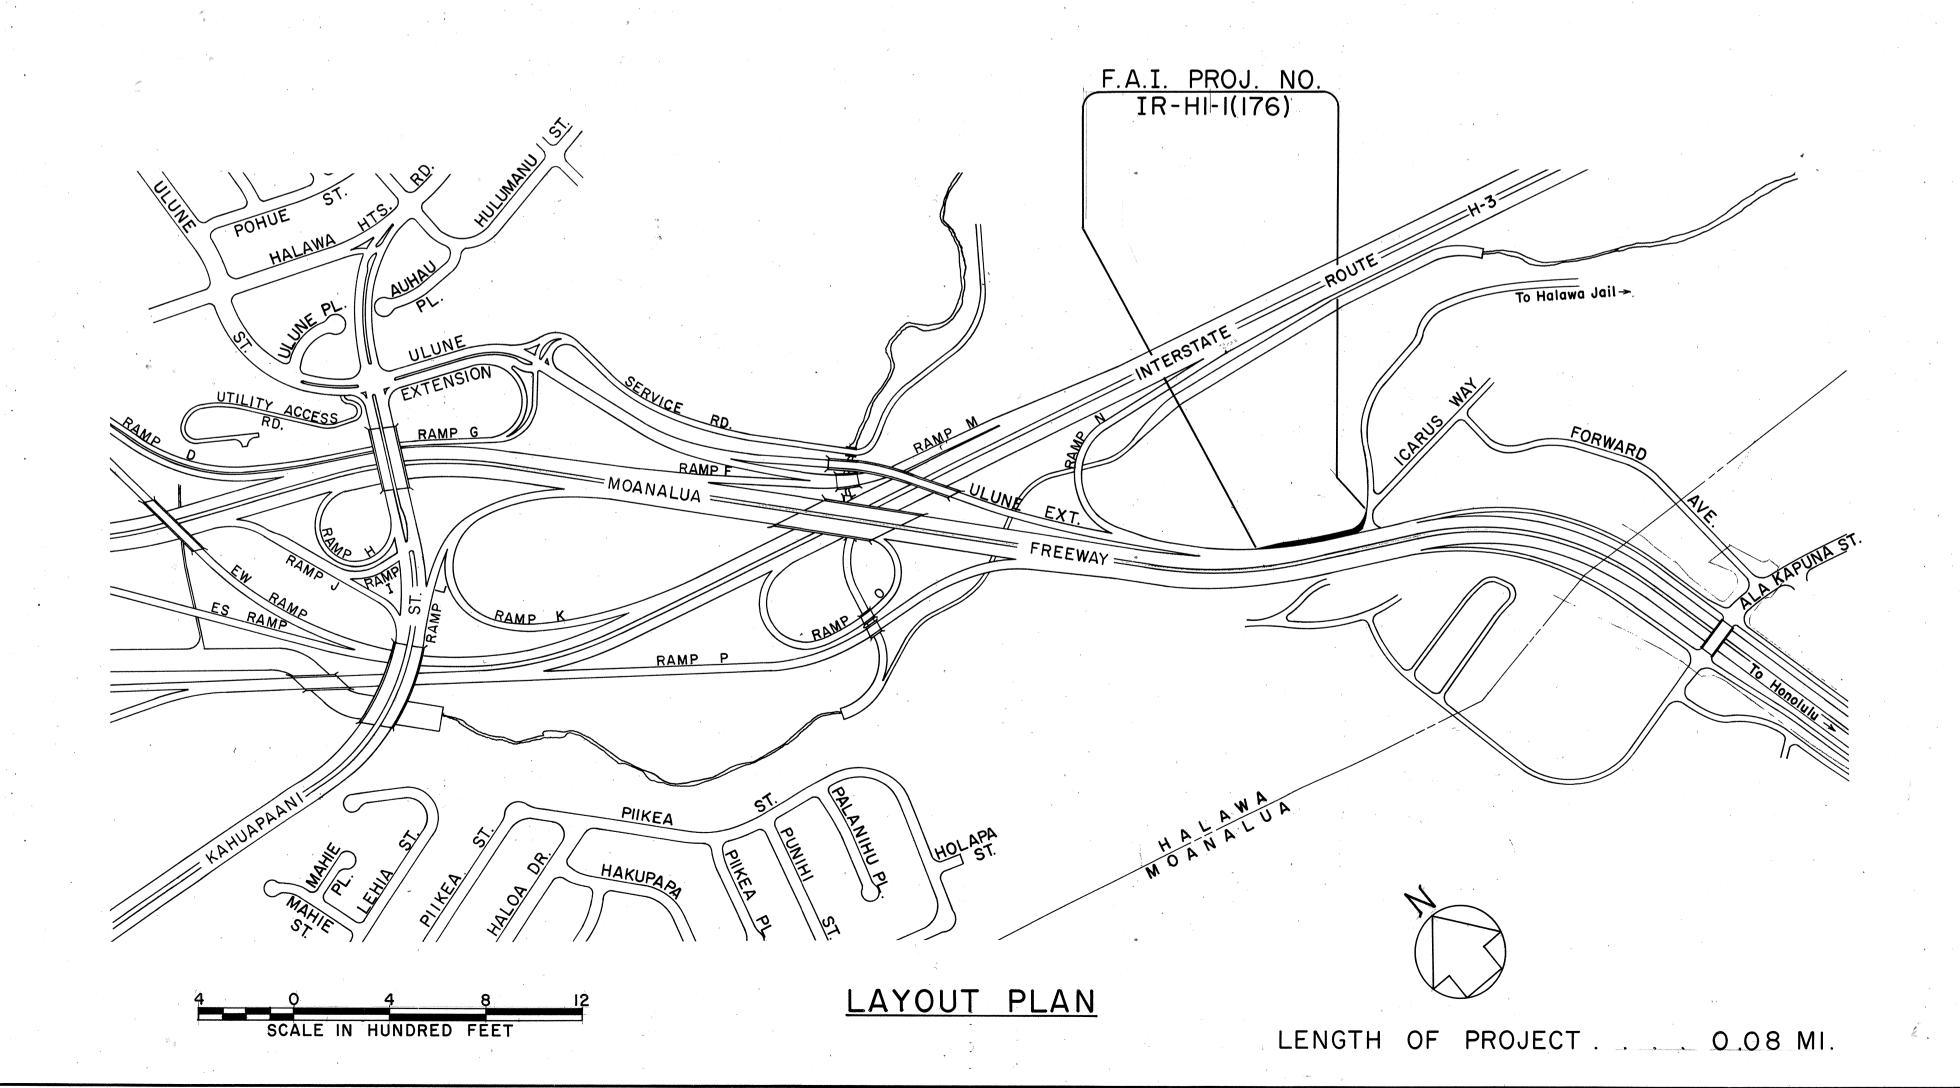

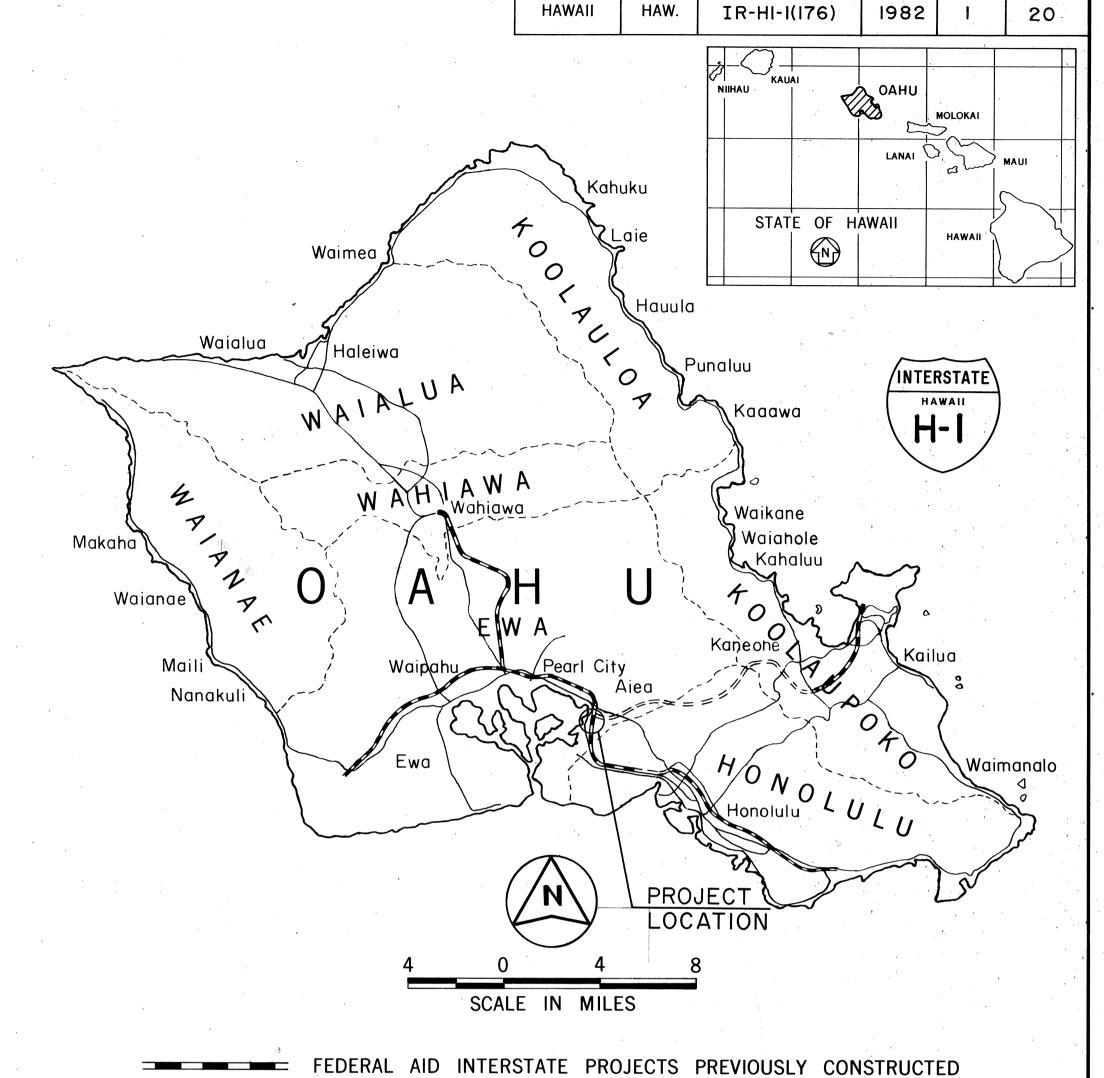

FED. ROAD DIST. NO.

FISCAL SHEET TOTAL YEAR NO. SHEETS

FED. AID PROJ. NO.

DESIGN DESIGNATION

OR UNDER CONSTRUCTION

CURRENT ADT (1981) 8,570 DESIGN ADT (1991) 10,070 D NOT APPLICABLE T₂₄ 4 %

CHANGES MADE DURING CONSTRUCTION HAVE BEEN INCORPORATED ON THESE PLANS EXCEPT CHANGES IN THE ORIGINAL THEORETICAL QUAN-TITLES. FOR ACTUAL QUANTITIES, REFER TO PROJECT LEDGER AND/OR COMPUTATION BOOK.

RESIDENT ENGINEER

DEPARTMENT OF TRANSPORTATION FEDERAL HIGHWAY ADMINISTRATION **APPROVED:** nearthus 5/26/82 DATE

TO DIVISION ADMINISTRATOR

PART	MENT	OF	TRAN	ISPOF	RTATI	ON 🕝
	STATE	E OF	HA\	WAII		*
ROVE	D:					
me	s K	26	m	as	57/2	482
	ROVE	STATE ROVED:	STATE OF ROVED:	STATE OF HAY	STATE OF HAWAII	