

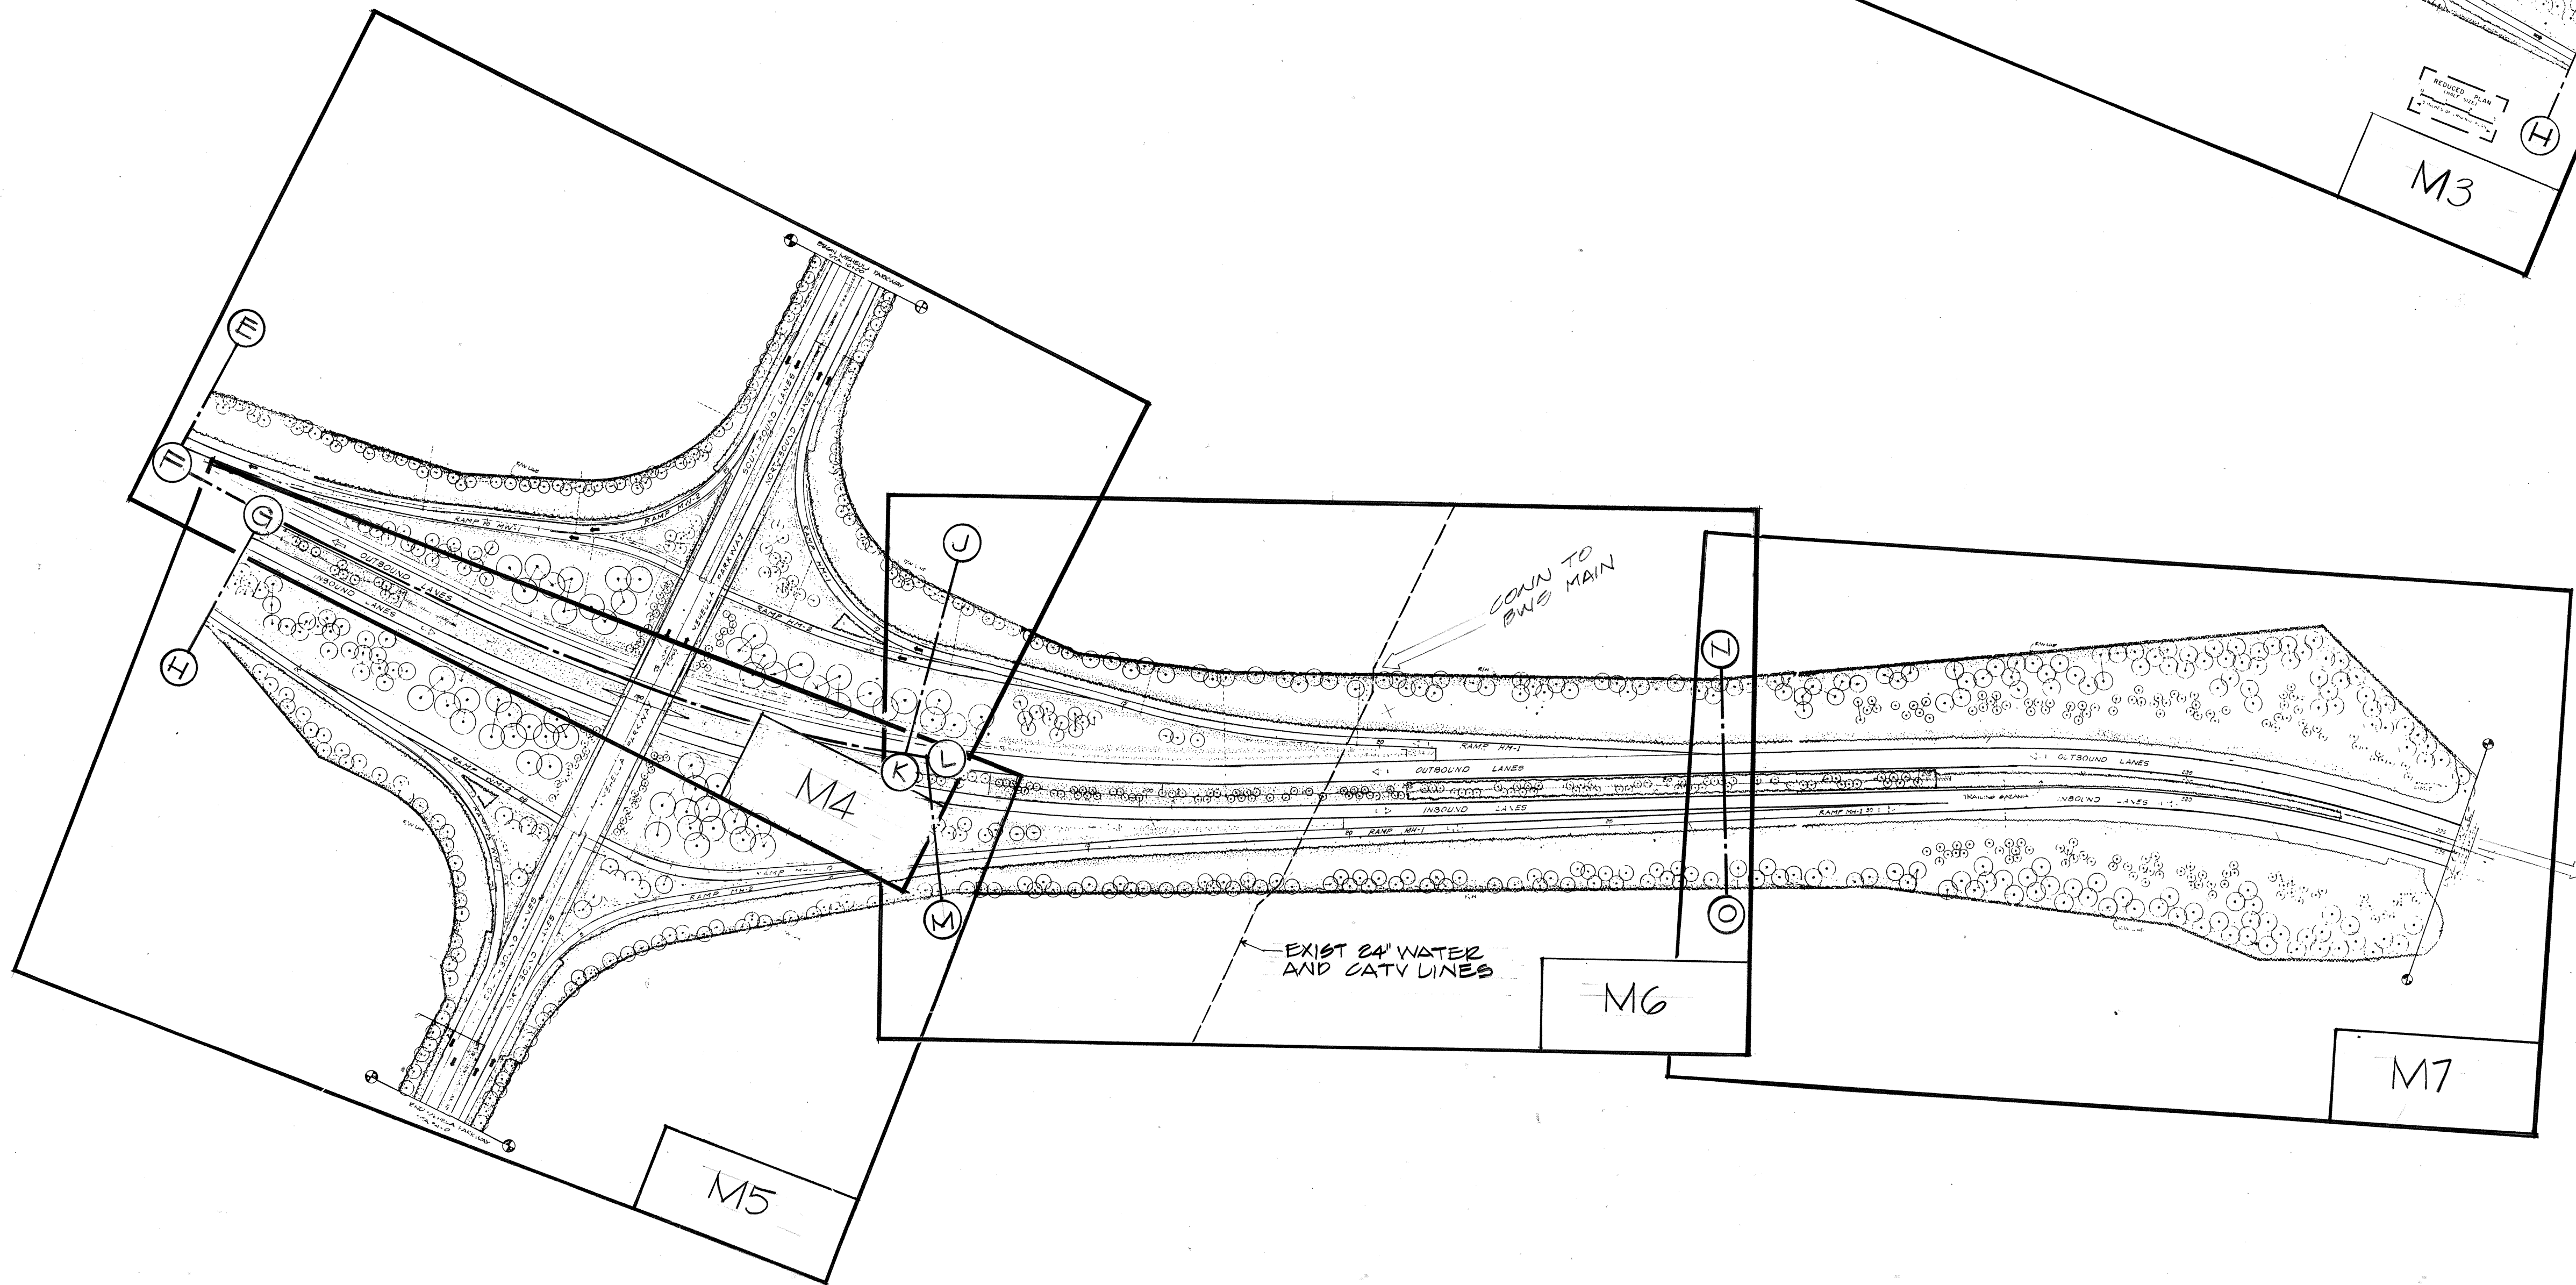


FED. ROAD DIST. NO.	STATE	FED. AID PROJ. NO.	FISCAL YEAR	SHEET NO.	TOTAL SHEETS
HAWAII	HAW.	I-H2-1(13):4	1977	10	34

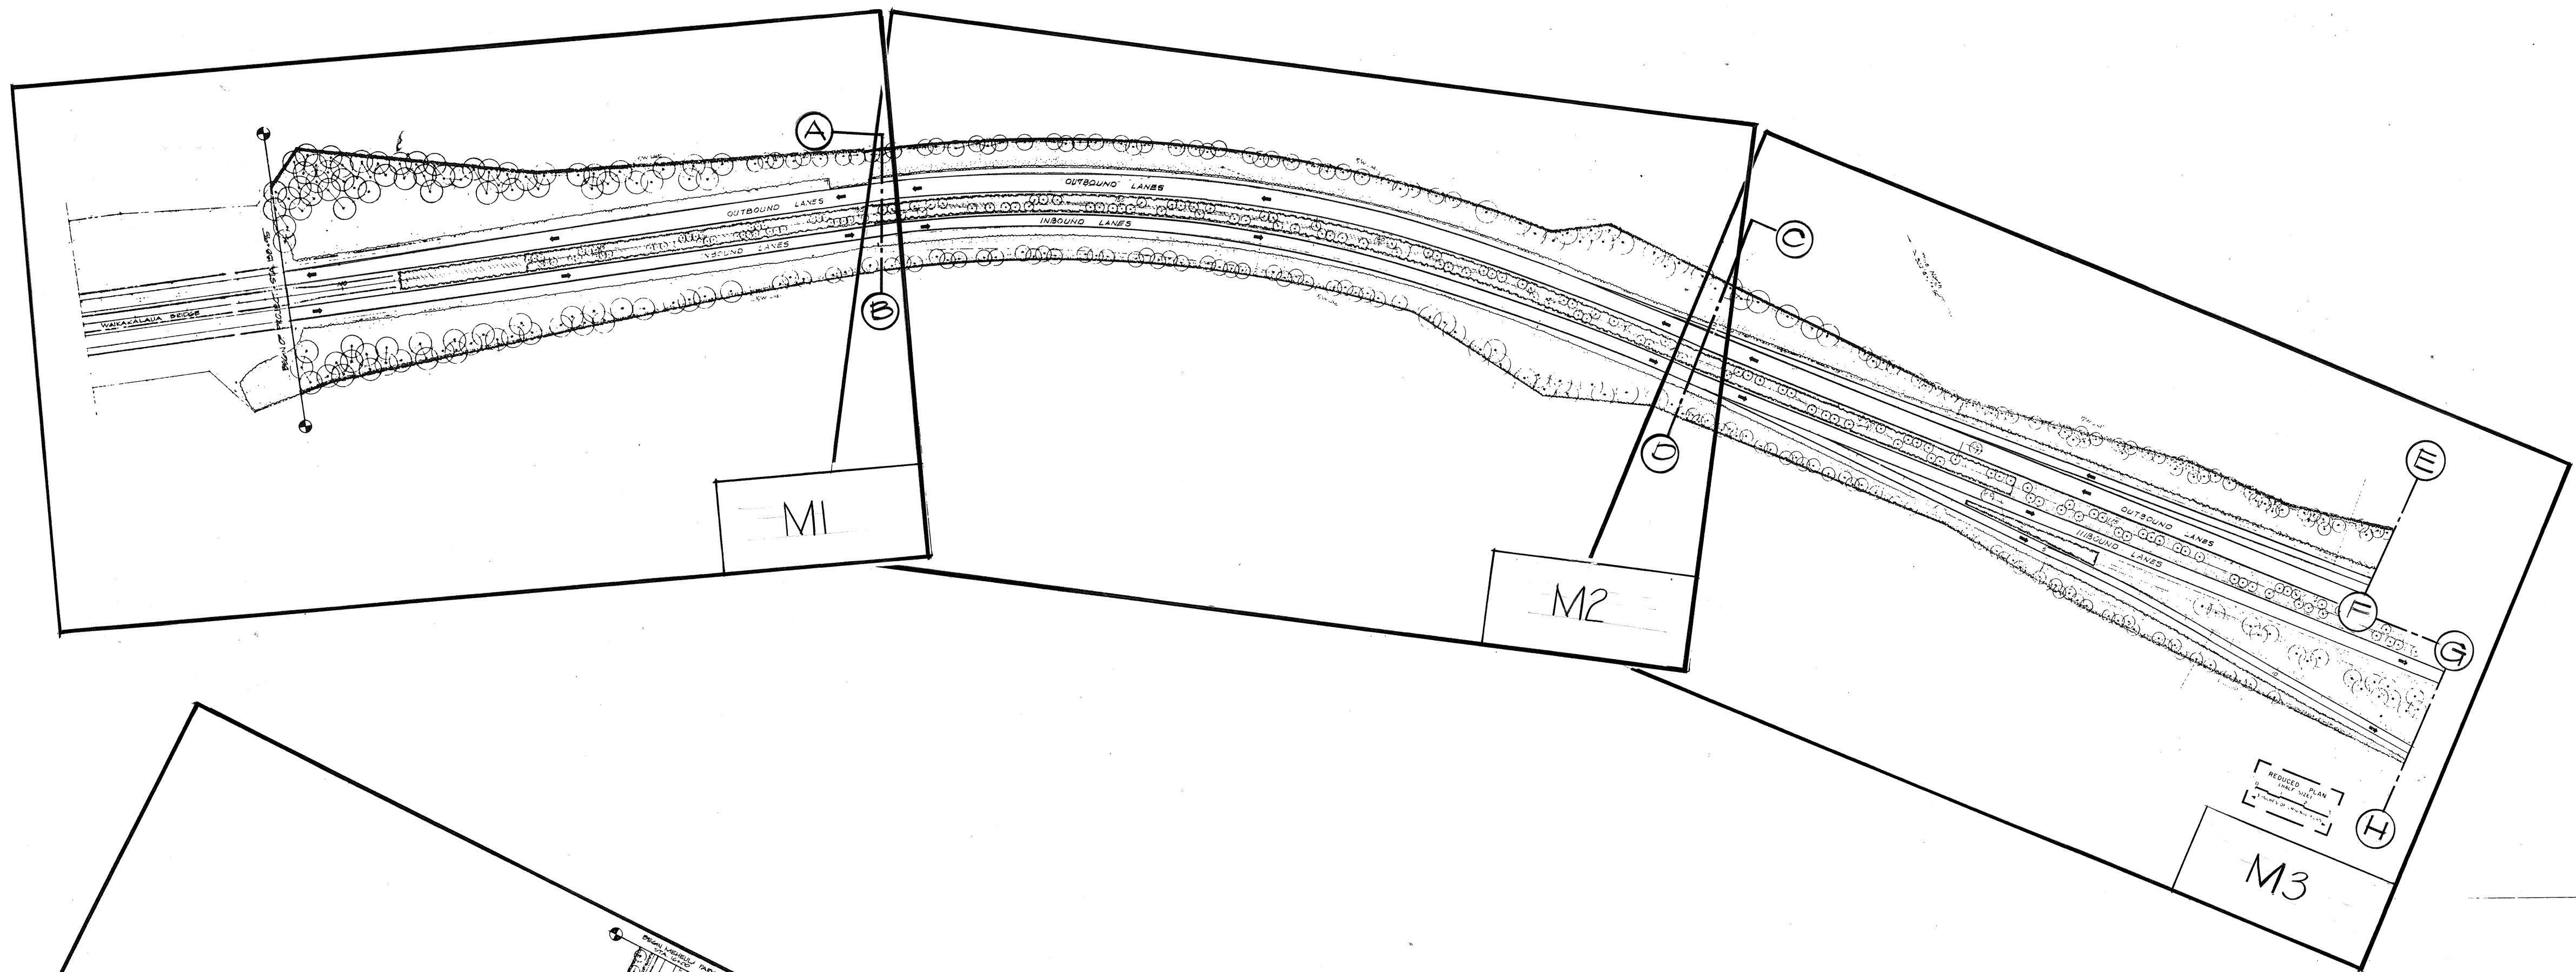

DATE	BY
DESIGNED BY	
TRACED BY	
NOTED BY	
CHECKED BY	

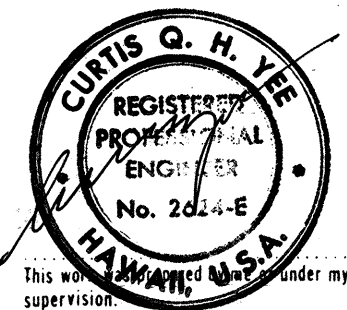

STATE OF HAWAII
DEPARTMENT OF TRANSPORTATION
HIGHWAYS DIVISION


PROJECT NO. I-H2-1(13):4

MILILANI INTERCHANGE


KEY SHEET

SHEET No. 10 OF 25 SHEETS

FED. ROAD DIST. NO.	STATE	FED. AID PROJ. NO.	FISCAL YEAR	SHEET NO.	TOTAL SHEETS
HAWAII	HAW.	I-42-1(13):4	1977	11	34

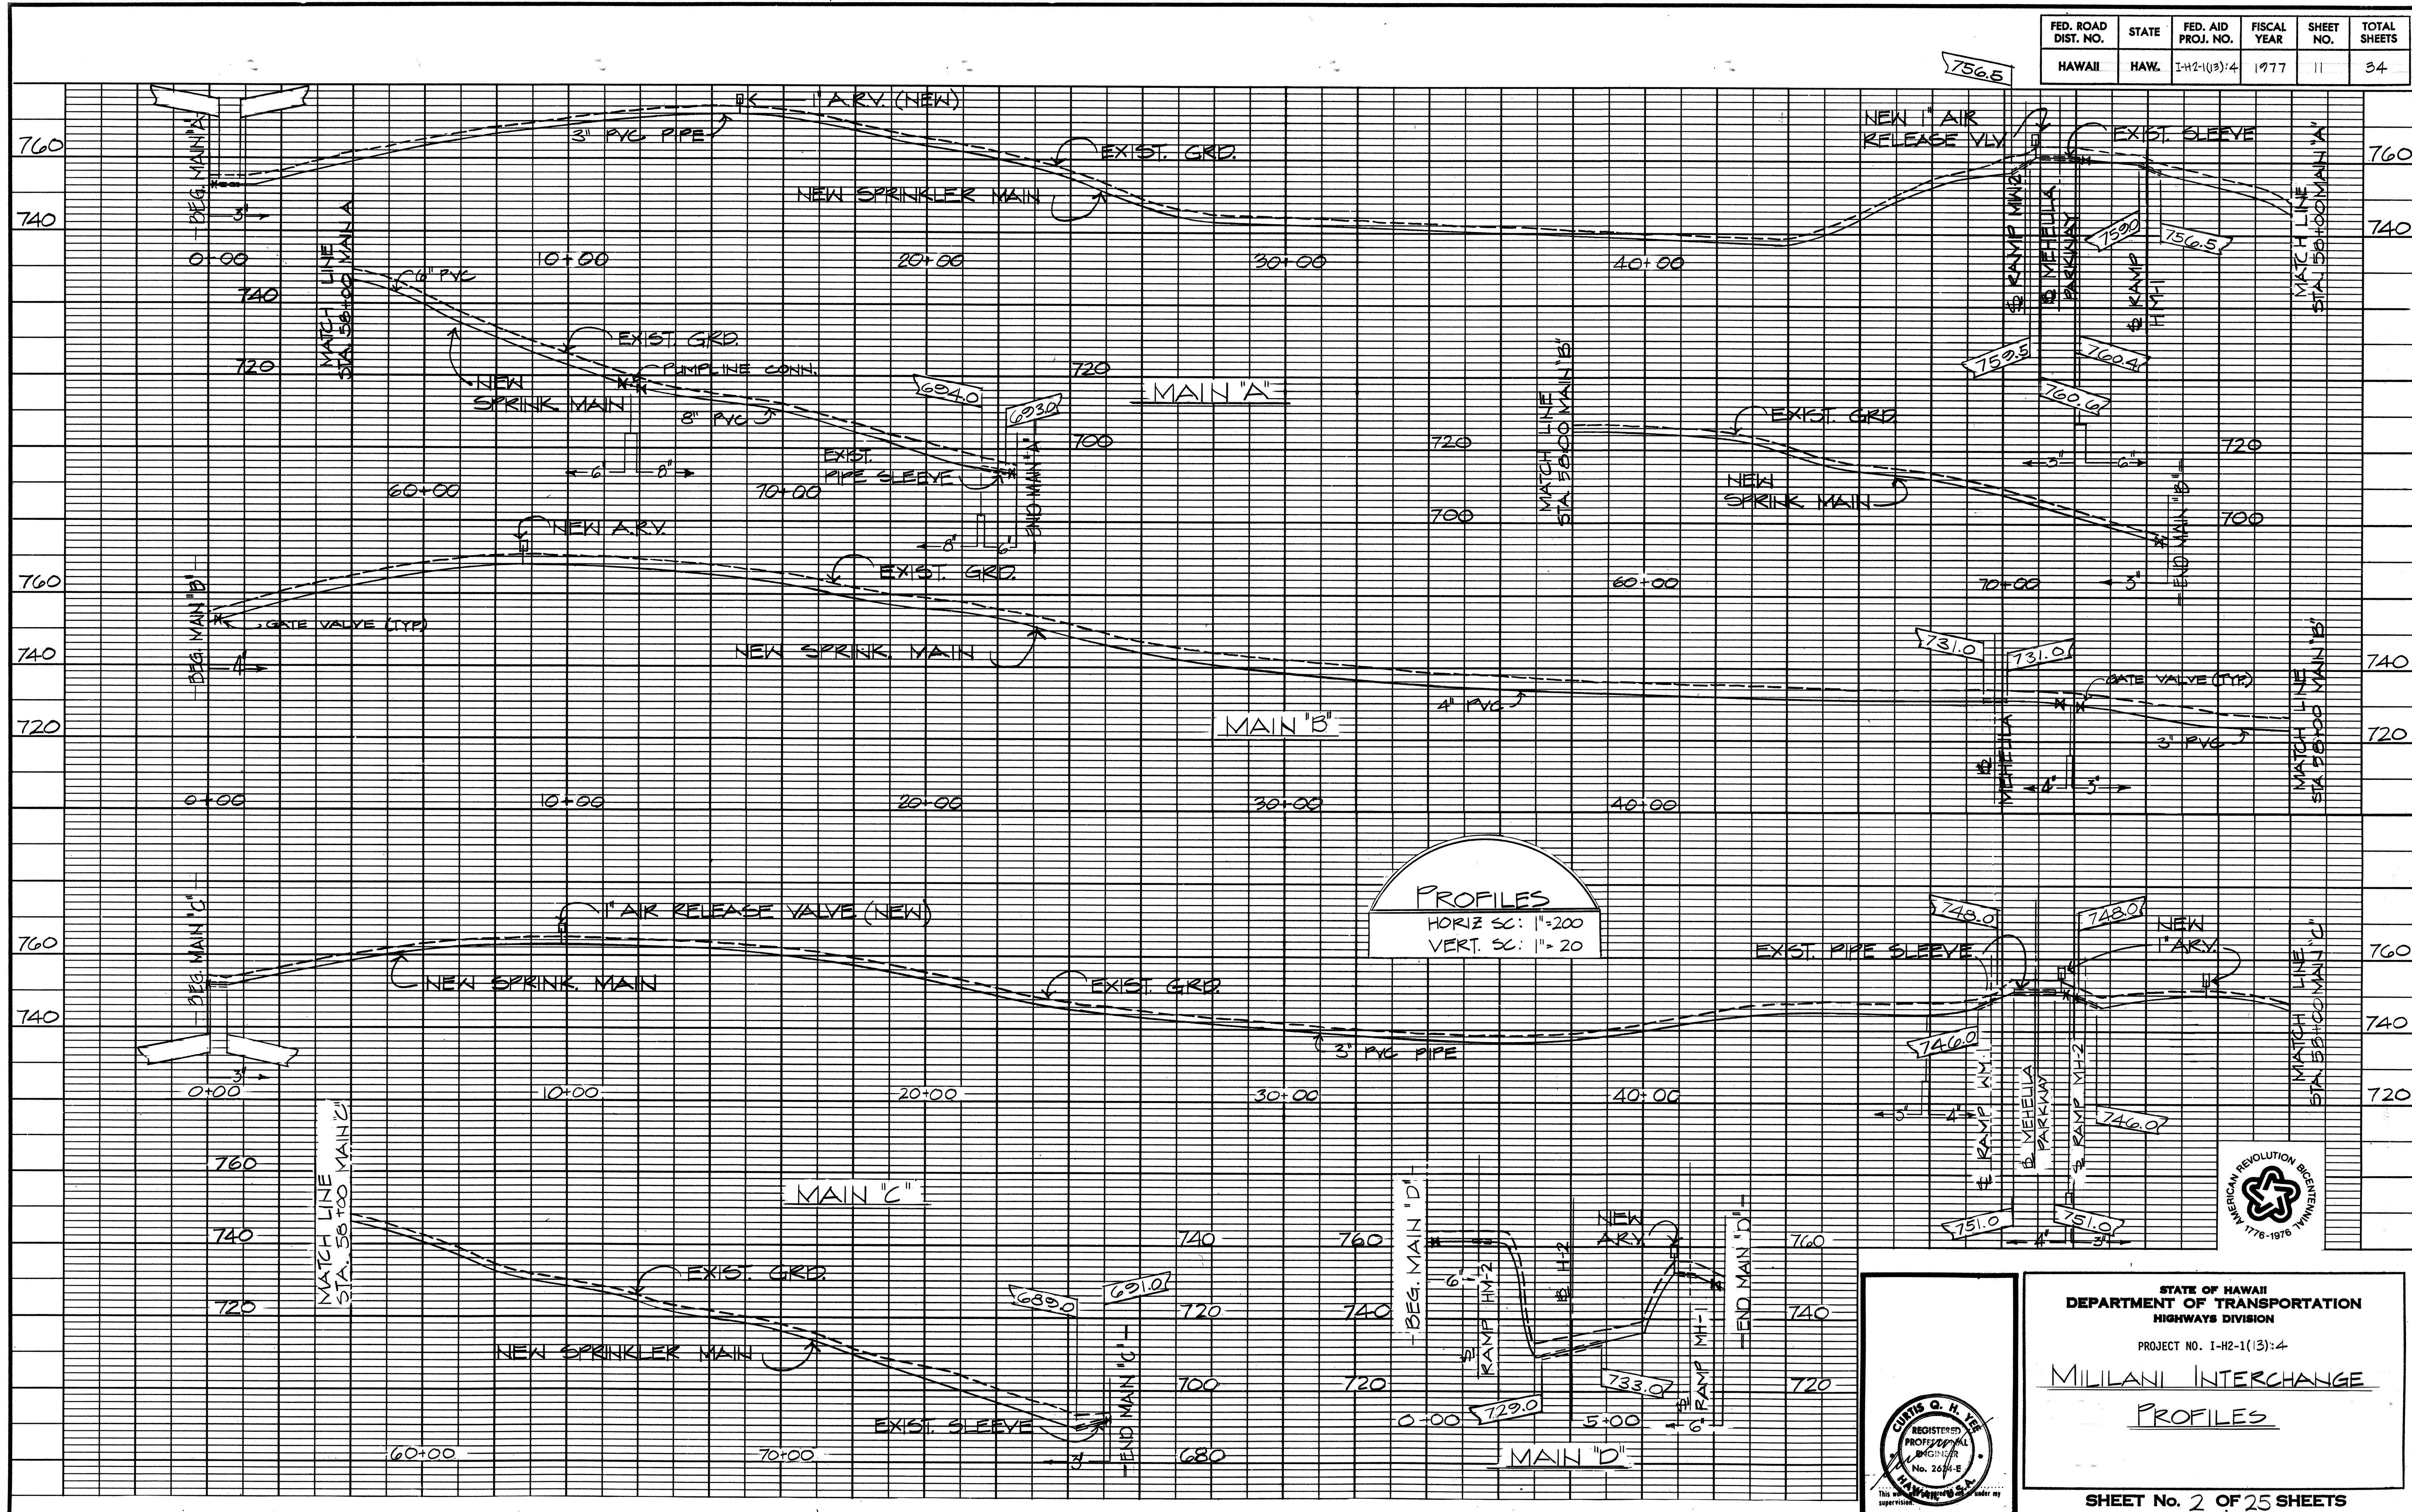

ORIGINAL PLAN	DATE
DRAWN BY	
CHECKED BY	
NOTES BOOK	
CHECKED BY	
No.	

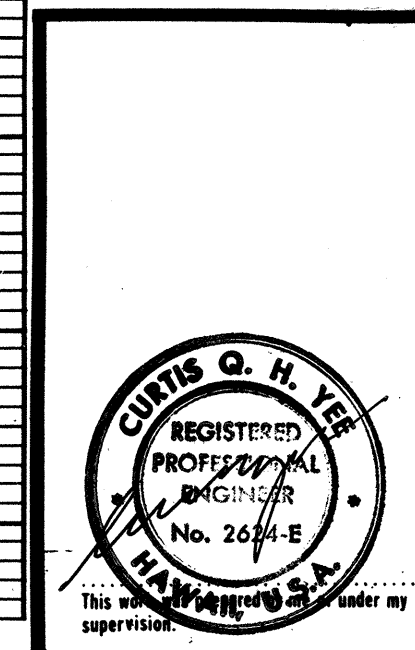

STATE OF HAWAII
 DEPARTMENT OF TRANSPORTATION
 HIGHWAYS DIVISION

PROJECT NO. I-42-1(13):4

MILILANI INTERCHANGE

PROFILES

SHEET No. 2 OF 25 SHEETS

GENERAL NOTES

1. EARTH SLOPES AND OTHER AREAS EXPOSED BY GRADING SHALL BE PLANTED WITH GRASS OR SUITABLE GROUND COVER AS SOON AS PRACTICAL FOLLOWING COMPLETION OF GRADING OPERATIONS IN ACCORDANCE WITH LAND-SCAPING REQUIREMENTS.
2. THE CONTRACTOR SHALL BE RESPONSIBLE FOR CONFORMATION TO CHAPTER 37 & 37A OF THE PUBLIC HEALTH REGULATIONS, DEPARTMENT OF HEALTH, STATE OF HAWAII.
3. ALL EXCAVATION IN AREAS PREVIOUSLY PLANTED WITH VEGETATION SHALL BE RETURNED TO ITS ORIGINAL STATE BY THE CONTRACTOR, EITHER BY REPLANTING OR SODDING. THE CONTRACTOR SHALL REMAIN RESPONSIBLE FOR THE RESTORATION AND ANY ASSOCIATED DAMAGE, UNTIL SUCH TIME THAT THE PLANTING HAS RETURNED TO ITS ORIGINAL STATE, AS DETERMINED BY THE STATE.
4. THE CONTRACTOR SHALL BE RESPONSIBLE FOR ALL DAMAGES, INJURIES, DEATHS, ETC., RESULTING FROM ACCIDENTS TO PROPERTY, PERSONNEL, EXISTING UTILITIES, FACILITIES, AND APPURTENANCES. HE SHALL HOLD HARMLESS THE STATE OF HAWAII, THE UNITED STATES GOVERNMENT, THE ENGINEER, AND ALL THEIR EMPLOYEES FROM SUITS, DAMAGES RESULTING THEREFROM.
5. UTILITIES SHOWN ON THE PLANS ARE FOR INFORMATIONAL PURPOSES ONLY, AND NO GUARANTEES ARE MADE AS TO THE ACCURACY OF THEIR LOCATIONS. IT SHALL BE THE RESPONSIBILITY OF THE CONTRACTOR TO COORDINATE WITH THE APPROPRIATE COMPANIES OR AGENCIES OF THE GOVERNMENT TO VERIFY THE LOCATIONS OF THE UTILITIES IN THE FIELD. THE CONTRACTOR SHALL MAINTAIN COORDINATION WITH THE UTILITY COMPANIES AND/OR AGENCIES THROUGHOUT THE DURATION TO THE PROJECT TO SEE THAT NONE OF THE UTILITIES PASSING THROUGH OR ADJACENT TO THE PROJECT SITE ARE INTERFERED WITH OR DAMAGED IN ANY WAY.
6. THE CONTRACTOR SHALL VERIFY ALL LINES, GRADES, AND DIMENSIONS ON THE JOB AND TO COORDINATE ALL WORK WITH TRADES AND UTILITIES.
7. THE CONTRACTOR SHALL SECURE PERMISSION AND CLEARANCES FROM ALL GOVERNMENTAL AND/OR PRIVATE AGENCIES OR COMPANIES CONCERNED WITH THE WORK. HE SHALL SECURE AND PAY FOR ALL FEES AND PERMITS REQUIRED FOR THE CONSTRUCTION ON THIS PROJECT.
8. IT SHALL BE THE RESPONSIBILITY OF THE CONTRACTOR TO AFFORD COMPLETE AND ADEQUATE PROTECTION AND SAFETY FOR HIS WORKING PERSONNEL AND THE PUBLIC AT ALL TIMES DURING THE CONSTRUCTION PERIOD.
9. THE CONTRACTOR SHALL DEWATER ALL TRENCHES AS REQUIRED FOR INSTALLATION AND TESTING OF PIPELINES AND FACILITIES.
10. THE CONTRACTOR SHALL COORDINATE ALL WORK WITH OTHER CONTRACTORS.
11. IN THE DIRECTION OF FLOW ALONG ANY LINE, DIAMETRIC PIPE SIZE SHALL REMAIN THE SAME OR SHALL DECREASE, AS SHOWN ON THE PLANS, UNLESS SPECIFICALLY CALLED FOR, IN NO CASE SHALL A PIPE OF ONE DIAMETER PRECEDE A PIPE OF A LARGER DIAMETER.
12. PRESSURE REDUCING VALVES SHALL BE SET AT PRESSURES INDICATED ON THE PLANS. ADJUSTMENTS TO THE INDICATED PRESSURES SHALL BE DONE UNDER DYNAMIC CONDITIONS, AS SHALL THE SETTING OF THE INDICATED PRESSURE BE DONE.
13. SCHEDULE 40 PVC PIPE WITH SOLVENT WELD CONNECTIONS SHALL BE USED UNLESS OTHERWISE CALLED FOR. SCHEDULE 40 PVC PIPE SHALL NOT BE THREADED, WHERE THREADED CONNECTIONS ARE REQUIRED, SCHEDULE 80 PIPE OR A THREADED ADAPTER SHALL BE USED, AT THE CONTRACTOR'S OPTION. SOLVENT WELD CONNECTIONS SHALL BE MADE ACCORDING TO MANUFACTURER'S INSTRUCTIONS.
14. ALL SPRINKLER HEADS SHALL BE INSTALLED TRUE AND PLUMB, AND SHALL NOT BE INSTALLED PERPENDICULAR TO THE FINISHED GRADE EXCEPT IN THE CASE WHERE THE GRADE IS DEAD LEVEL OR UNLESS OTHERWISE CALLED FOR IN THE PLANS.
15. ANY SPRINKLER HEAD SELECTED BY THE CONTRACTOR HAVING A VARIABLE FLOW ADJUSTMENT FEATURE SHALL BE ADJUSTED UNDER DYNAMIC CONDITIONS.
16. FOR PIPELINES CROSSING EXISTING PAVED ROADWAYS, WORK SHALL BE PERFORMED AS FOLLOWS:
A. A.C. PAVEMENT SHALL BE NEATLY CUT.
B. TRENCH BACKFILL MATERIAL AND A.C. PAVEMENT SHALL MATCH THE EXISTING PAVEMENT STRUCTURE.
17. ALL PIPING DESIGNS ARE BASED ON THE HAZEN-WILLIAMS FORMULA:
 $v = 1.318C_r^{0.63} s^{0.54}$ AND $h_f = 1(0.00515Q/D^{2.63C})^{1.852}$
HAZEN-WILLIAMS COEFFICIENT USED: FOR PVC PIPE, $C = 130$
18. CONTROL VALVES, GATE VALVES, VALVE ASSEMBLY UNITS, AIR RELIEF VALVES AND REMOTE CONTROL VALVES SHOWN ADJACENT TO CURBS, SHOULDERS AND PAVED AREAS SHALL BE INSTALLED 4 FEET FROM THE ABOVE MENTIONED.
19. UNLESS OTHERWISE NOTED, SPRINKLERS SHALL BE INSTALLED 5 FEET FROM CURBS, SHOULDERS, STRUCTURES, DITCHES, SLOPE PAVING AND GUARD RAILS; AND A MAXIMUM OF 3 FEET FROM FENCES. SPRINKLERS SHOWN ADJACENT TO SIDEWALKS SHALL BE INSTALLED A MAXIMUM OF 12 INCHES FROM THE SIDEWALK. SPRINKLERS SHOWN ADJACENT TO CURBS IN GORE AREAS AND IN THE MEDIAN SHALL BE INSTALLED A MAXIMUM OF 12 INCHES FROM THE CURB UNLESS OTHERWISE NOTED.
20. ALL POP-UP SPRINKLER HEADS SHALL BE INSTALLED ON FLEX SWING JOINTS. SWING JOINTS WILL BE THE SAME SIZE AS THE RISER CONNECTION.


22. USE OF WATER STREAM BREAK-UP DEVICES WILL BE PERMITTED TO ADJUST COVERAGE RADII OF SPRINKLER HEADS.
21. DEFINITION OF TERMS USED:
A. 'CENTRAL PROGRAMMER' AND 'MASTER CONTROLLER' ARE THE SAME, AND THE TERMS USED INTERCHANGEABLY.
B. 'FIELD CONTROLLER' AND 'SATELLITE CONTROLLER' ARE THE SAME, AND THE TERMS USED INTERCHANGEABLY.
C. 'AUTOMATIC CONTROL VALVE' AND 'REMOTE CONTROL VALVE' ARE THE SAME, AND THE TERMS USED INTERCHANGEABLY.

STRUCTURAL NOTES

1. 4000 P.S.F. SOIL BEARING PRESSURE ASSUMED. IF CONDITIONS INDICATE OTHERWISE, OR REQUIRE MODIFICATION, THE CONTRACTOR SHALL NOTIFY THE ENGINEER IMMEDIATELY.
2. ALL CONCRETE MASONRY UNIT (CMU) WALLS SHALL BE VERTICALLY REINFORCED WITH 2-#4 BARS, 4'-0" ON CENTERS, AND THE SAME AT ALL CORNERS, ENDS, AND OPENINGS UNLESS OTHERWISE SHOWN. FILL CELLS CONTAINING REINFORCEMENT WITH CONCRETE GROUT. CONCRETE MASONRY UNIT HORIZONTAL REINFORCEMENT SHALL BE INSTALLED CONTINUOUSLY EVERY OTHER COURSE.
3. THE CONTRACTOR SHALL VERIFY SIZE AND LOCATION OF SLOTS, ANCHORS, OPENINGS, ETC., RELATING MECHANICAL, ELECTRICAL, AND ARCHITECTURAL WORK BEFORE POURING CONCRETE.
4. SLEEVES THROUGH STRUCTURAL MEMBERS SHALL NOT BE INSTALLED BY THE CONTRACTOR WITHOUT WRITTEN APPROVAL OF THE ENGINEER.
5. ALL CONCRETE USED ON THIS PROJECT SHALL BE CLASS B STRENGTH.
6. MINIMUM REINFORCING BAR COVERAGE: 3" FOR MEMBERS CAST AGAINST AND PERMANENTLY EXPOSED TO EARTH, 3/4" ON SLABS, AND 1-1/2" ELSEWHERE UNLESS OTHERWISE INDICATED.
7. ALL FOOTINGS SHALL EXTEND 6" INTO ORIGINAL UNDISTURBED EARTH. UNDER NO CIRCUMSTANCES SHALL ANY FOOTING BE PLACED ON FILL MATERIAL.
8. ALL CONCRETE USED ON THIS PROJECT SHALL BE POURED MONOLITHICALLY.
9. ALL REINFORCEMENT SHALL BE PLACED TRUE AND PLUMB.
10. ALL REINFORCING BARS SHALL BE SECURELY TIED AND HELD IN PLACE TO PREVENT ANY MOVEMENT OR DIS-PLACEMENT WHILE CONCRETE IS BEING POURED.
11. ALL ON-GRADE SLABS SHALL HAVE A MINIMUM REINFORCEMENT OF 6"x6" #10x#10 WELDED WIRE MESH.
12. LAP BARS 24 DIAMETERS OR 12", WHICHEVER IS GREATER.
13. CHAMFER ALL EXPOSED CONCRETE CORNERS 3/4"x3/4".

SPRINKLER DESIGNATION	SPRINKLER TYPE	DISCHARGE	OPERATING PRESSURE	RADIUS
S12	IMPACT, FULL CIRCLE	6.3 GPM	40 PSI	40 FT.
S13	IMPACT, FULL CIRCLE	3.8	30	30
*S14	IMPACT, FULL CIRCLE	2.4	35	20
S15	SPRAY, FULL CIRCLE	4.8	30	15
S16	SPRAY, FULL CIRCLE	1.5	15	10
S22	IMPACT, PART CIRCLE	6.3	40	40
S23	IMPACT, PART CIRCLE	3.8	30	30
*S24	IMPACT, PART CIRCLE	1.3	35	20
S25	SPRAY, PART CIRCLE	3.6	30	15
S26	SPRAY, PART CIRCLE	1.2	15	10
P12	ROTOR POP-UP, FULL CIRCLE	6.4	40	40
P13	ROTOR POP-UP, FULL CIRCLE	3.9	30	30
*P14	ROTOR POP-UP, FULL CIRCLE	2.4	35	20
P15	SPRAY POP-UP, FULL CIRCLE	4.8	30	15
P16	SPRAY POP-UP, FULL CIRCLE	1.5	15	10
P22	ROTOR POP-UP, PART CIRCLE	6.4	40	40
P23	ROTOR POP-UP, PART CIRCLE	3.9	30	30
*P24	ROTOR POP-UP, PART CIRCLE	1.3	35	20
P25	SPRAY POP-UP, PART CIRCLE	3.6	30	15
P26	SPRAY POP-UP, PART CIRCLE	1.2	15	10

* HEADS MAY BE IMPACT OR SPRAY TYPES, SUBJECT TO APPROVAL.

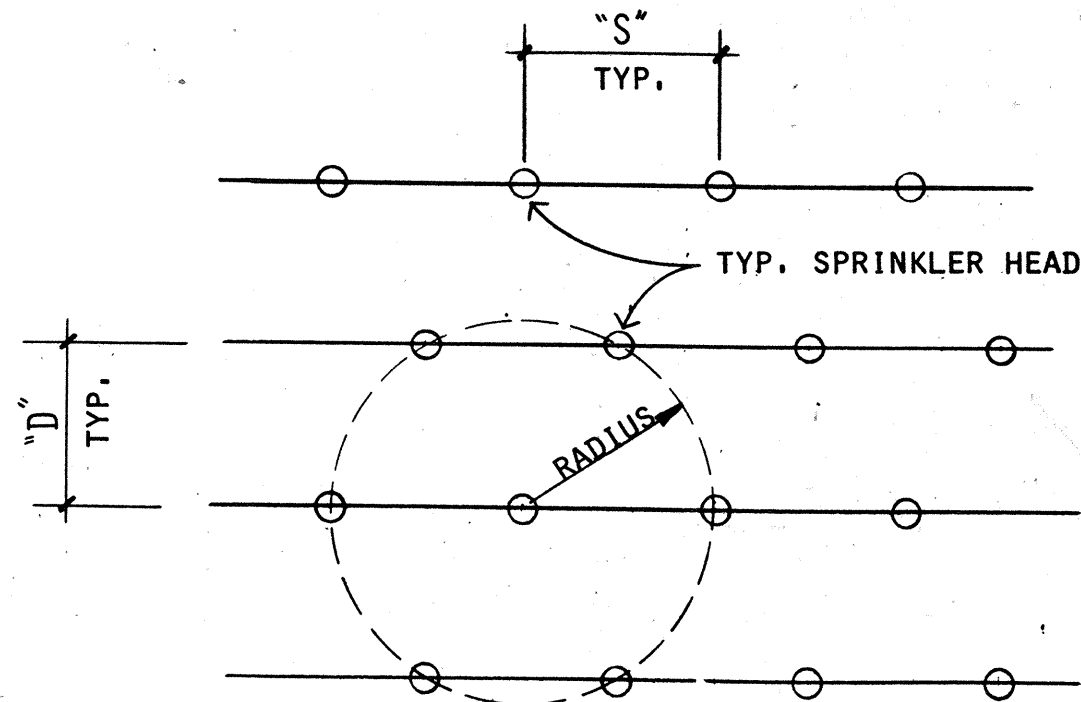


SPRINKLER RADIUS	"S"	"D"
10 FT.	10'-0"	8'-8"
15	15'-0"	13'-0"
20	20'-0"	17'-4"
30	30'-0"	26'-0"
40	40'-0"	35'-8"

TYPICAL SPRINKLER SPACING


FED. ROAD DIST. NO.	STATE	FED. AID PROJ. NO.	FISCAL YEAR	SHEET NO.	TOTAL SHEETS
HAWAII	HAW.	I-42-1(13):4	1977	12	34

IRRIGATION LEGEND


- FULL CIRCLE POP-UP SPRINKLER HEAD
◐ HALF CIRCLE POP-UP SPRINKLER HEAD
⊞ FULL CIRCLE FIXED SPRINKLER HEAD
⊞ HALF CIRCLE FIXED SPRINKLER HEAD
■ FIELD CONTROLLER
◆ DRIP IRRIGATION VALVE ASSEMBLY UNIT
⋈ GATE VALVE
⊙ ELECTRIC REMOTE CONTROL VALVE
○ HOSE BIBB
— PLASTIC PIPE SUPPLY LINE
~ DRIP IRRIGATION LINE - PLASTIC
⊙ AIR RELIEF AND VACUUM RELIEF VALVE
⋈ PRESSURE RELIEF VALVE
⊞ BACKFLOW PREVENTER

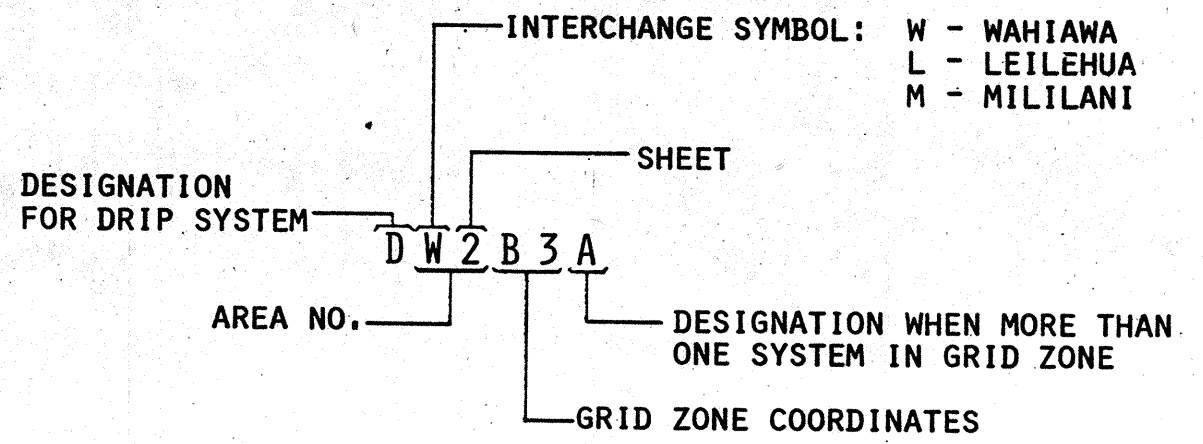

EXPLANATION OF IRRIGATION SYSTEM DESIGNATIONS

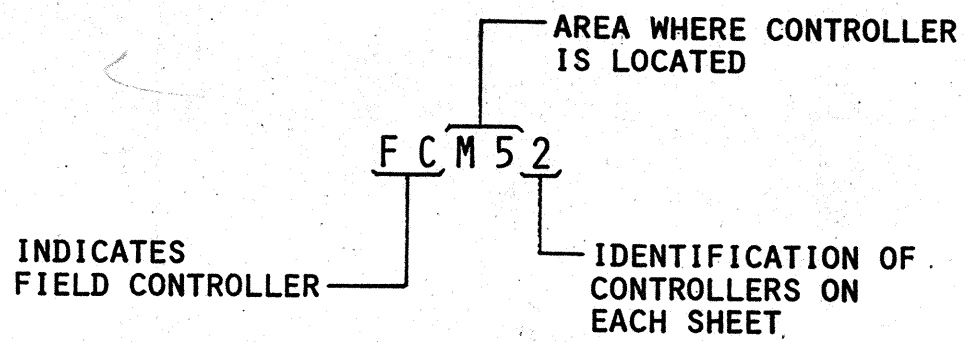


EXPLANATION OF FIELD CONTROLLER DESIGNATIONS

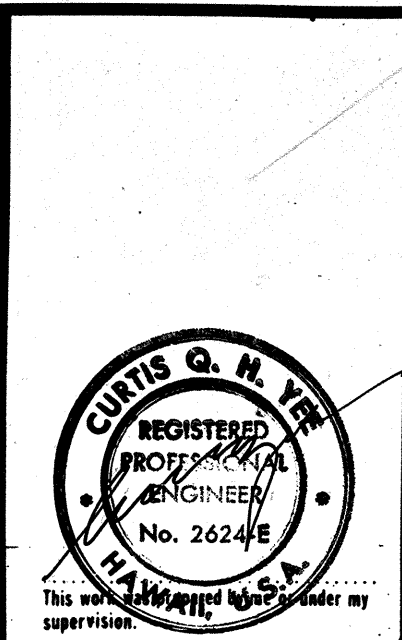

STATE OF HAWAII
DEPARTMENT OF TRANSPORTATION
HIGHWAYS DIVISION
PROJECT NO. I-42-1(13):4
MILILANI INTERCHANGE
GENERAL NOTES
SHEET No. 3 OF 25 SHEETS



FED. ROAD DIST. NO.	STATE	FED. AID PROJ. NO.	FISCAL YEAR	SHEET NO.	TOTAL SHEETS
HAWAII	HAW.	I-H2-1(13):4	1977	14	34

DATE	REVISION
11/17/76	523 Sprinkler Heads in BANK Nos. M2B3, M2D3, M2F3, M2G4 & M2I5 replaced with P23 Sprinkler Heads per Addendum No. 1

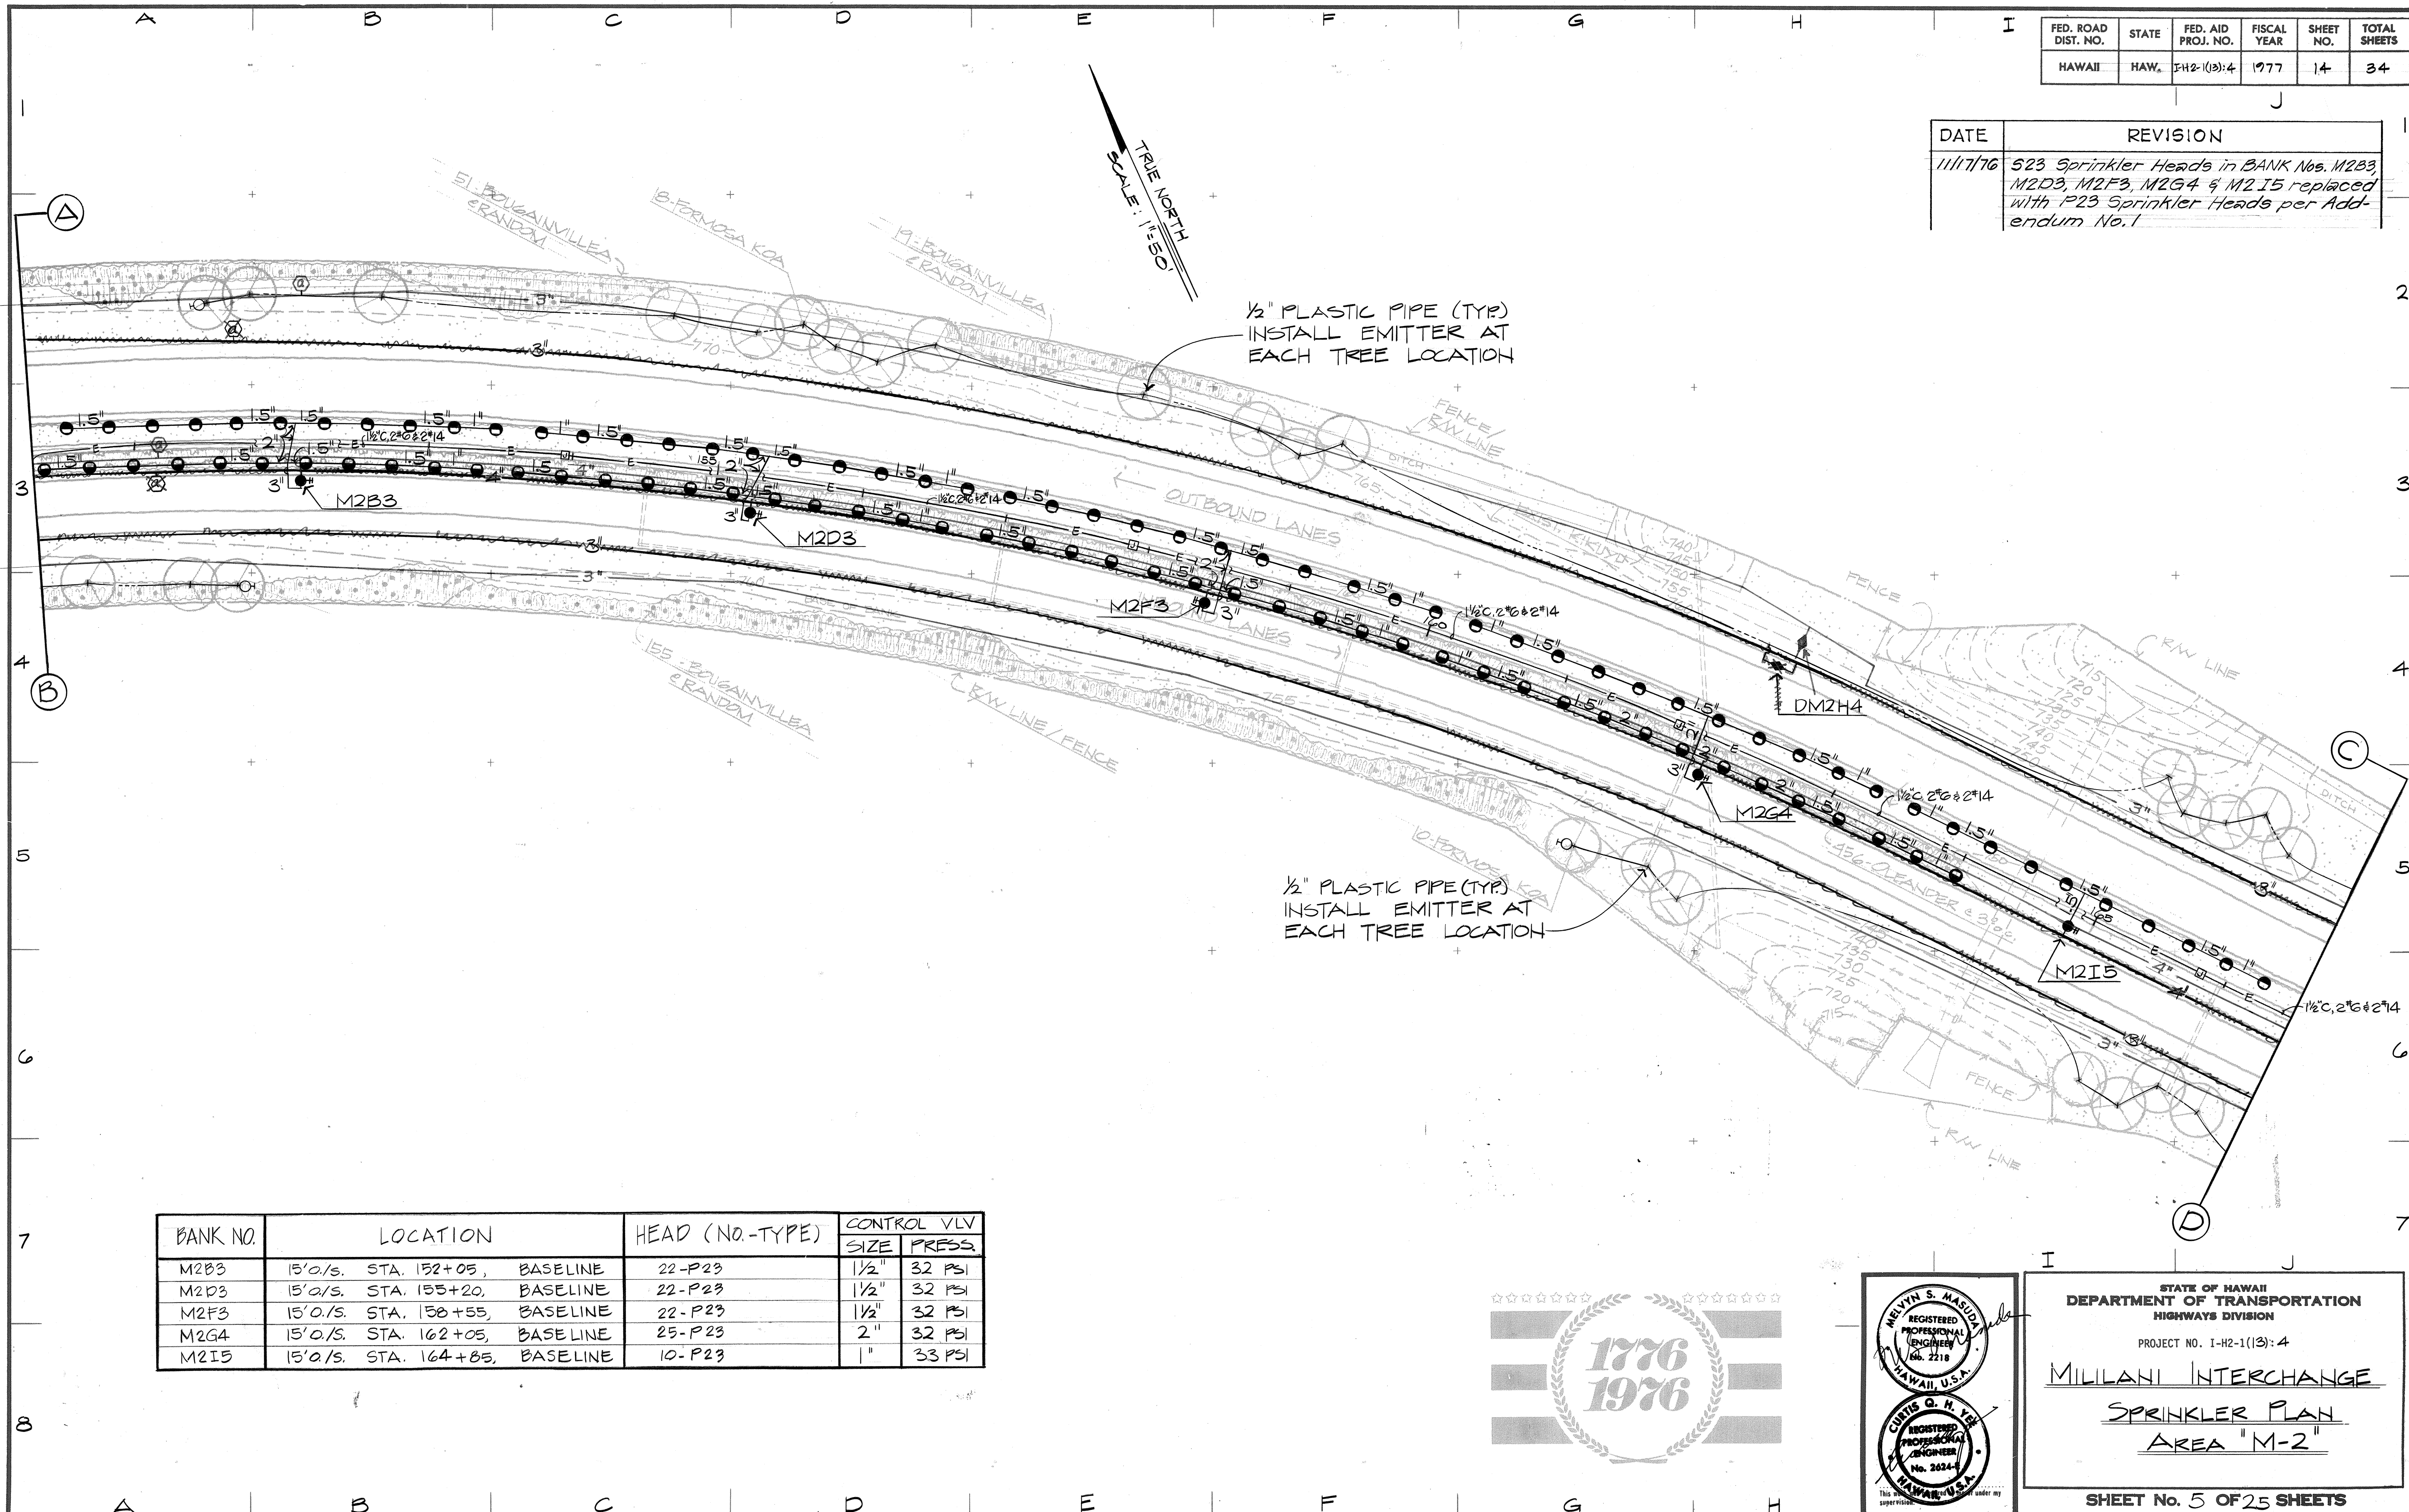

BANK NO.	LOCATION	HEAD (NO.-TYPE)	CONTROL VLV	
			SIZE	PRESS.
M2B3	15' O/S. STA. 152+05, BASELINE	22-P23	1 1/2"	32 PSI
M2D3	15' O/S. STA. 153+20, BASELINE	22-P23	1 1/2"	32 PSI
M2F3	15' O/S. STA. 158+55, BASELINE	22-P23	1 1/2"	32 PSI
M2G4	15' O/S. STA. 162+05, BASELINE	25-P23	2"	32 PSI
M2I5	15' O/S. STA. 164+85, BASELINE	10-P23	1"	33 PSI

DESIGNED BY	DATE
DRAWN BY	
CHECKED BY	
IN CHARGE	
NOTED BY	
NO.	

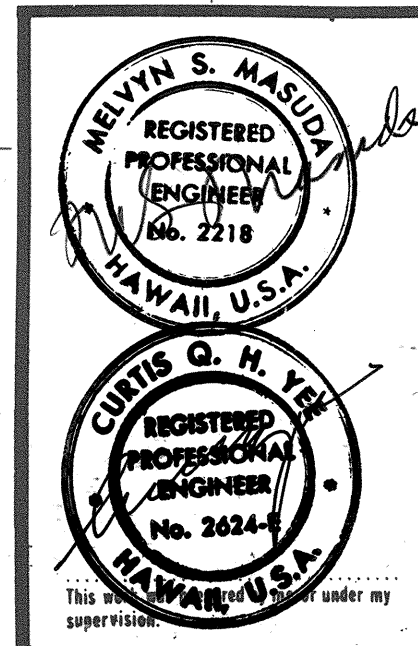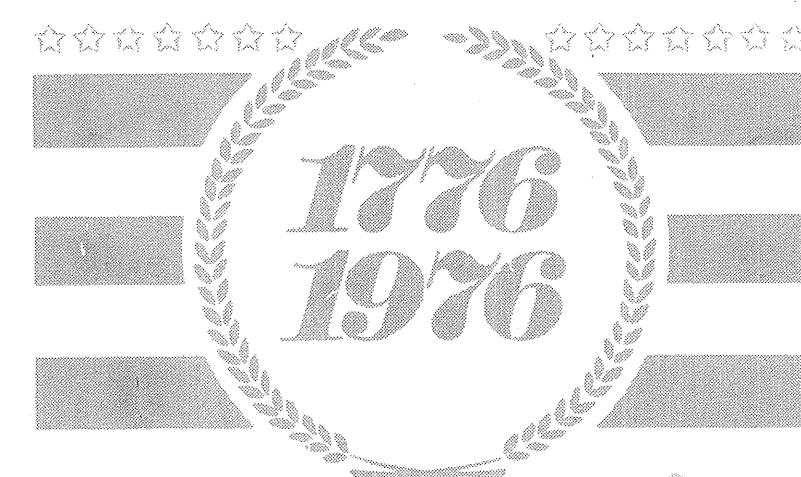

STATE OF HAWAII
DEPARTMENT OF TRANSPORTATION
HIGHWAYS DIVISION

PROJECT NO. I-H2-1(13):4

MILILANI INTERCHANGE

SPRINKLER PLAN

AREA "M-2"


SHEET No. 5 OF 25 SHEETS

DATE	REVISION
11/17/76	523 Sprinkler Heads in BANK Nos. M3B4, M3C4, M3E4, M3F4, M3H4 & M3I4 replaced with P23 Sprinkler Heads per Addendum No.1

FED. ROAD DIST. NO.	STATE	FED. AID PROJ. NO.	FISCAL YEAR	SHEET NO.	TOTAL SHEETS
HAWAII	HAW.	I-H2-1(13):4	1977	15	34

TRUE NORTH
SCALE: 1"=50'


1/2" PLASTIC PIPE (TYF)
INSTALL EMITTER AT
EACH TREE LOCATION

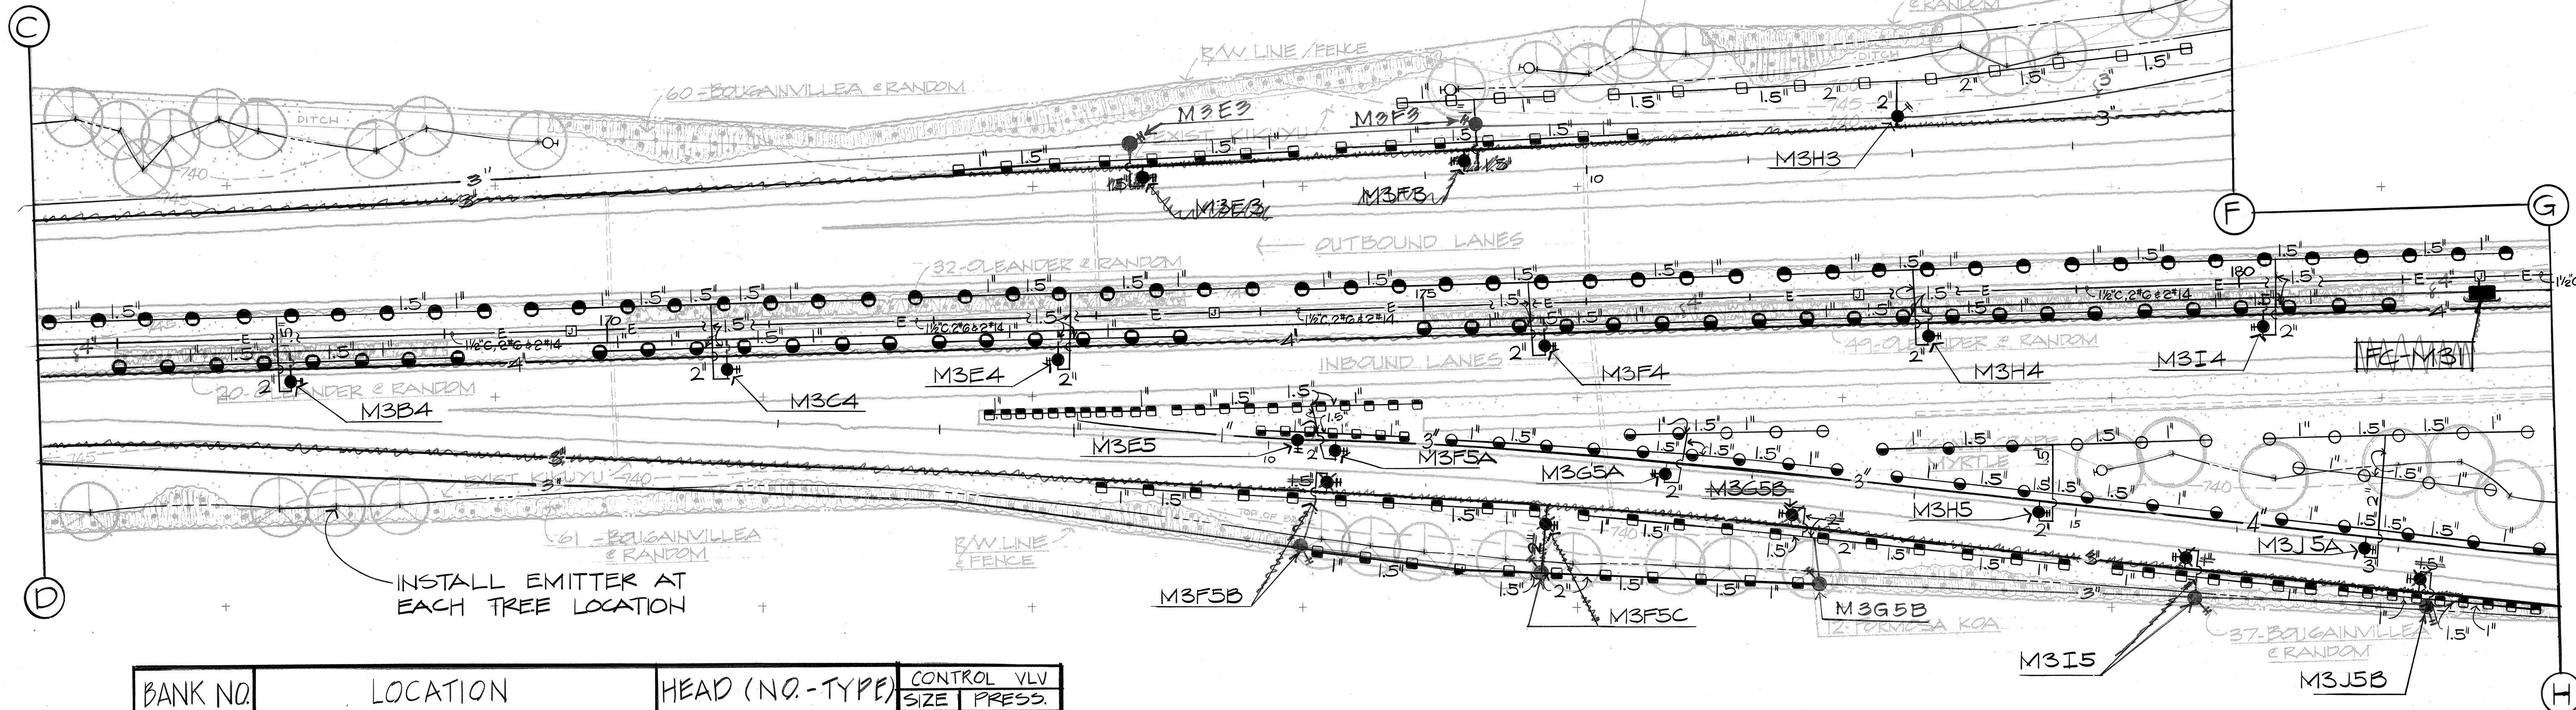

INSTALL EMITTER AT
EACH TREE LOCATION

BANK NO.	LOCATION	HEAD (NO.-TYPE)	CONTROL VLV SIZE	PRESS.
M3B4	15' O/S. STA. 167+98, BASELINE	10-P23	1/2"	32 PSI
M3C4	15' O/S. STA. 170+65, BASELINE	15-P23	1/2"	32 PSI
M3E3	94' O/S. STA. 173+23, BASELINE	8-S23	1"	32 PSI
M3E4	15' O/S. STA. 172+85, BASELINE	14-P23	1"	32 PSI
M3E5	57' O/S. STA. 172+88, BASELINE	11-S26	1"	27 PSI
M3F3	19' O/S. STA. 9+30, RAMP MW-I	4-S13, 7-S23	1"	33 PSI
M3F4	15' O/S. STA. 175+67, BASELINE	17-P23	1/2"	32 PSI
M3F5A	9' O/S. STA. 10+30, RAMP WM-I	18-S23	1/2"	32 PSI
M3F5B	34' O/S. STA. 10+30, RAMP WM-I	10-S23	1"	33 PSI
M3F5C	73' O/S. STA. 11+73, RAMP WM-I	11-S23	1"	35 PSI
M3G5A	9' O/S. STA. 12+56, RAMP WM-I	3-P13, 11-P23	1"	34 PSI
M3G5B	34' O/S. STA. 13+33, RAMP WM-I	11-S23	1"	33 PSI
M3H3	45' O/S. STA. 11+93, RAMP MW-I	10-S12	1/2"	44 PSI
M3H4	15' O/S. STA. 178+00, BASELINE	14-P23	1"	32 PSI
M3H5	9' O/S. STA. 14+85, RAMP WM-I	3-P12, 9-P22	1/2"	45 PSI
M3I4	15' O/S. STA. 180+22, BASELINE	16-P23	1/2"	32 PSI
M3I5	34' O/S. STA. 15+80, RAMP WM-I	7-S24	1"	30 PSI
M3J5A	9' O/S. STA. 16+87, RAMP WM-I	9-P12, 5-P22	1/2"	45 PSI
M3J5B	30' O/S. STA. 17+22, RAMP WM-I	9-S23	1"	32 PSI

SURVEY PLOTTED BY	DATE
DRAWN BY	
DESIGNED BY	
QUANTITIES BY	
CHECKED BY	
ORIGINAL PLAN	
NOTE BOOK	
No.	

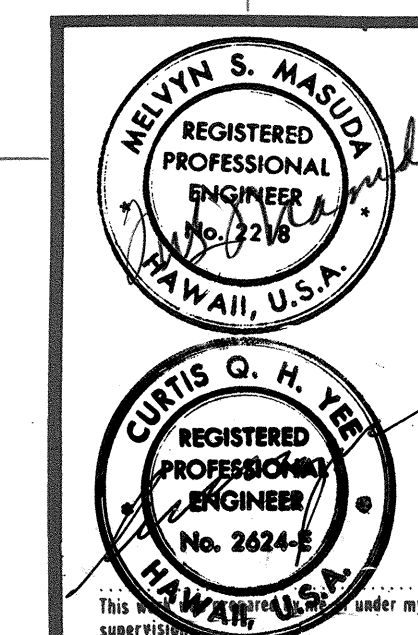

STATE OF HAWAII
DEPARTMENT OF TRANSPORTATION
HIGHWAYS DIVISION

PROJECT NO. I-H2-1(13):4

MILILANI INTERCHANGE


SPRINKLER PLAN

AREA "M-3"

SHEET No. 6 OF 25 SHEETS




FED. ROAD DIST. NO.	STATE	FED. AID PROJ. NO.	FISCAL YEAR	SHEET NO.	TOTAL SHEETS
HAWAII	HAW.	I-H2-1(13)-4	1977	17	34

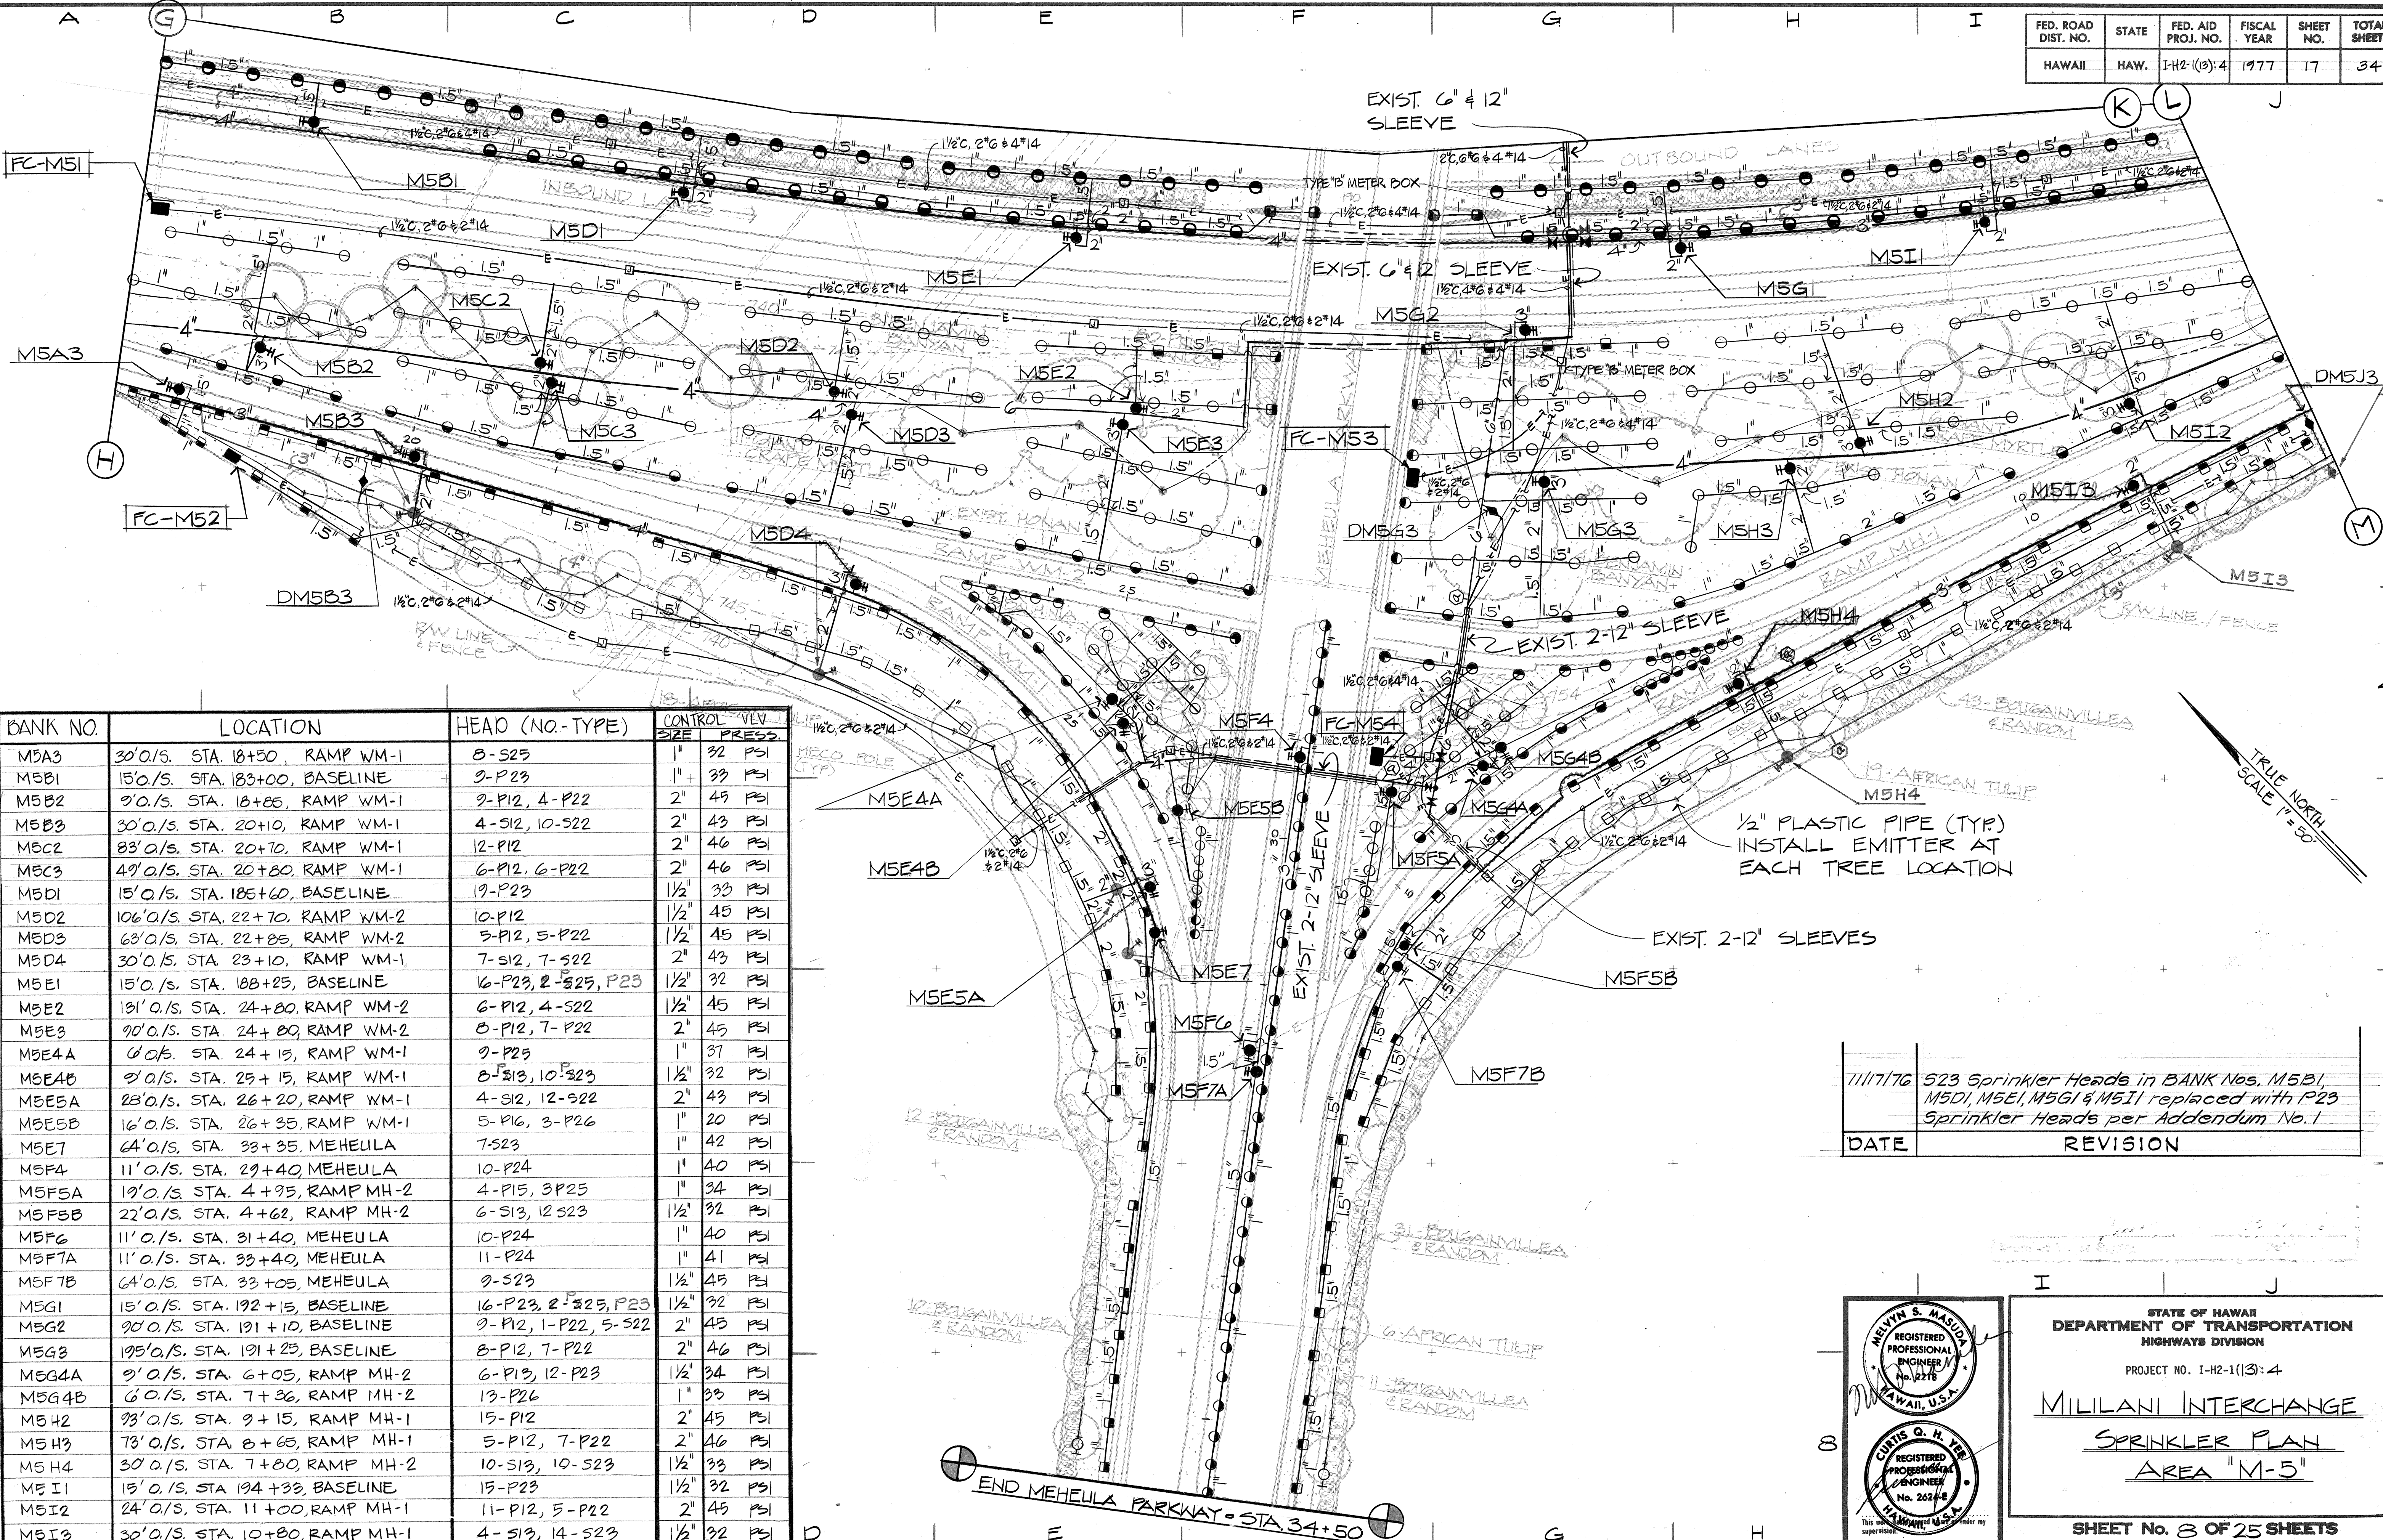

BANK NO.	LOCATION	HEAD (NO.-TYPE)	CONTROL VALV	
			SIZE	PRESS
M5A3	30' O/S. STA. 18+50, RAMP WM-1	8-S25	1"	32 PSI
M5B1	15' O/S. STA. 183+00, BASELINE	9-P23	1"	33 PSI
M5B2	30' O/S. STA. 18+05, RAMP WM-1	9-P12, 4-P22	2"	45 PSI
M5B3	30' O/S. STA. 20+10, RAMP WM-1	4-S12, 10-S22	2"	43 PSI
M5C2	83' O/S. STA. 20+70, RAMP WM-1	12-P12	2"	46 PSI
M5C3	49' O/S. STA. 20+80, RAMP WM-1	6-P12, 6-P22	2"	46 PSI
M5D1	15' O/S. STA. 186+60, BASELINE	9-P23	1 1/2"	33 PSI
M5D2	106' O/S. STA. 22+70, RAMP WM-2	10-P12	1 1/2"	45 PSI
M5D3	63' O/S. STA. 22+85, RAMP WM-2	5-P12, 5-P22	1 1/2"	45 PSI
M5D4	30' O/S. STA. 23+10, RAMP WM-1	7-S12, 7-S22	2"	43 PSI
M5E1	15' O/S. STA. 188+25, BASELINE	16-P23, 2-S25, P23	1 1/2"	32 PSI
M5E2	181' O/S. STA. 24+80, RAMP WM-2	6-P12, 4-S22	1 1/2"	45 PSI
M5E3	90' O/S. STA. 24+80, RAMP WM-2	8-P12, 7-P22	2"	45 PSI
M5E4A	6' O/S. STA. 24+15, RAMP WM-1	9-P25	1"	37 PSI
M5E4B	9' O/S. STA. 25+15, RAMP WM-1	8-S13, 10-S23	1 1/2"	32 PSI
M5E5A	23' O/S. STA. 26+20, RAMP WM-1	4-S12, 12-S22	2"	43 PSI
M5E5B	16' O/S. STA. 26+35, RAMP WM-1	5-P16, 3-P26	1"	20 PSI
M5E7	64' O/S. STA. 33+35, MEHEULA	7-S23	1"	42 PSI
M5F4	11' O/S. STA. 29+40, MEHEULA	10-P24	1"	40 PSI
M5F5A	19' O/S. STA. 4+95, RAMP MH-2	4-P15, 3-P25	1"	34 PSI
M5F5B	22' O/S. STA. 4+62, RAMP MH-2	6-S13, 12-S23	1 1/2"	32 PSI
M5F6	11' O/S. STA. 31+40, MEHEULA	10-P24	1"	40 PSI
M5F7A	11' O/S. STA. 33+40, MEHEULA	11-P24	1"	41 PSI
M5F7B	64' O/S. STA. 33+05, MEHEULA	9-S23	1 1/2"	45 PSI
M5G1	15' O/S. STA. 192+15, BASELINE	16-P23, 2-S25, P23	1 1/2"	32 PSI
M5G2	90' O/S. STA. 191+10, BASELINE	9-P12, 1-P22, 5-S22	2"	45 PSI
M5G3	195' O/S. STA. 191+25, BASELINE	8-P12, 7-P22	2"	46 PSI
M5G4A	9' O/S. STA. 6+05, RAMP MH-2	6-P13, 12-P23	1 1/2"	34 PSI
M5G4B	6' O/S. STA. 7+36, RAMP MH-2	13-P26	1"	33 PSI
M5H2	93' O/S. STA. 9+15, RAMP MH-1	15-P12	2"	45 PSI
M5H3	73' O/S. STA. 8+65, RAMP MH-1	5-P12, 7-P22	2"	46 PSI
M5H4	30' O/S. STA. 7+80, RAMP MH-2	10-S13, 10-S23	1 1/2"	33 PSI
M5I1	15' O/S. STA. 194+33, BASELINE	15-P23	1 1/2"	32 PSI
M5I2	24' O/S. STA. 11+00, RAMP MH-1	11-P12, 5-P22	2"	45 PSI
M5I3	30' O/S. STA. 10+80, RAMP MH-1	4-S13, 14-S23	1 1/2"	32 PSI

11/17/76	S23 Sprinkler Heads in BANK Nos. M5B1, M5D1, M5E1, M5G1 & M5I1 replaced with P23 Sprinkler Heads per Addendum No. 1
DATE	REVISION

DATE	_____
SURVEY PLANNED BY	_____
DESIGNED BY	_____
TRACED BY	_____
NOTED BY	_____
CHECKED BY	_____
IN CHARGE	_____

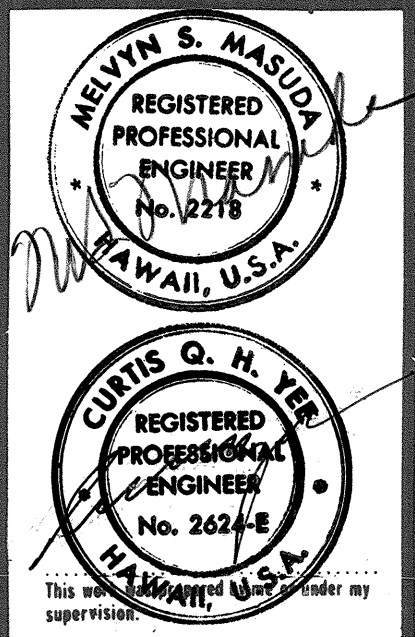


STATE OF HAWAII
DEPARTMENT OF TRANSPORTATION
HIGHWAYS DIVISION
PROJECT NO. I-H2-1(13)-4
MILILANI INTERCHANGE
SPRINKLER PLAN
AREA "M-5"
SHEET No. 8 OF 25 SHEETS

BANK NO.	LOCATION	HEAD (NO.-TYPE)	CONTROL VLV	
			SIZE	PRESS
M6A4	81' O/S. STA. 196+80, BASELINE	5-P12, 6-P22	1 1/2"	45 PSI
M6B3	31' O/S. STA. 13+42, RAMP HM-1	4-S12, 8-S22	1 1/2"	43 PSI
M6B4	158' O/S. STA. 196+60, BASELINE	6-P12, 6-P22	1 1/2"	45 PSI
M6B5	15' O/S. STA. 197+20, BASELINE	15-P23	1 1/2"	32 PSI
M6B6	24' O/S. STA. 13+58, RAMP MH-1	5-P13, 13-P23	1 1/2"	34 PSI
M6B7	42' O/S. STA. 13+20, RAMP MH-1	8-S13	1"	33 PSI
M6C4	103' O/S. STA. 198+70, INBOUND	5-P12, 9-P22	2"	45 PSI
M6C5	7' O/S. STA. 199+40, INBOUND	14-P23	1"	32 PSI
M6C6	55' O/S. STA. 15+65, RAMP MH-1	7-S12, 6-S22	2"	43 PSI
M6D3	60' O/S. STA. 16+80, RAMP HM-1	11-S13, 9-S23	1 1/2"	34 PSI
M6D4	103' O/S. STA. 200+80, INBOUND	11-P22	1 1/2"	45 PSI
M6D5	7' O/S. STA. 201+82, INBOUND	15-P23	1 1/2"	32 PSI
M6D6	21' O/S. STA. 16+32, RAMP MH-1	24-P25	1 1/2"	32 PSI
M6E4	103' O/S. STA. 202+75, INBOUND	12-P24	1"	35 PSI

DATE	REVISION
11/17/76	523 Sprinkler Heads in BANK Nos. M6B5, M6C5, M6D5, M6F5, M6G5 & M6I4 replaced with P23 Sprinkler Heads per Addendum No. 1 Reference (A) in grid F3 revised to read (H). Meter and connection in grid F3 revised to read "New 4" WATER METER AND CONNECTION."



FED. ROAD DIST. NO.	STATE	FED. AID PROJ. NO.	FISCAL YEAR	SHEET NO.	TOTAL SHEETS
HAWAII	HAW.	I-H2-1(13):4	1977	13	34

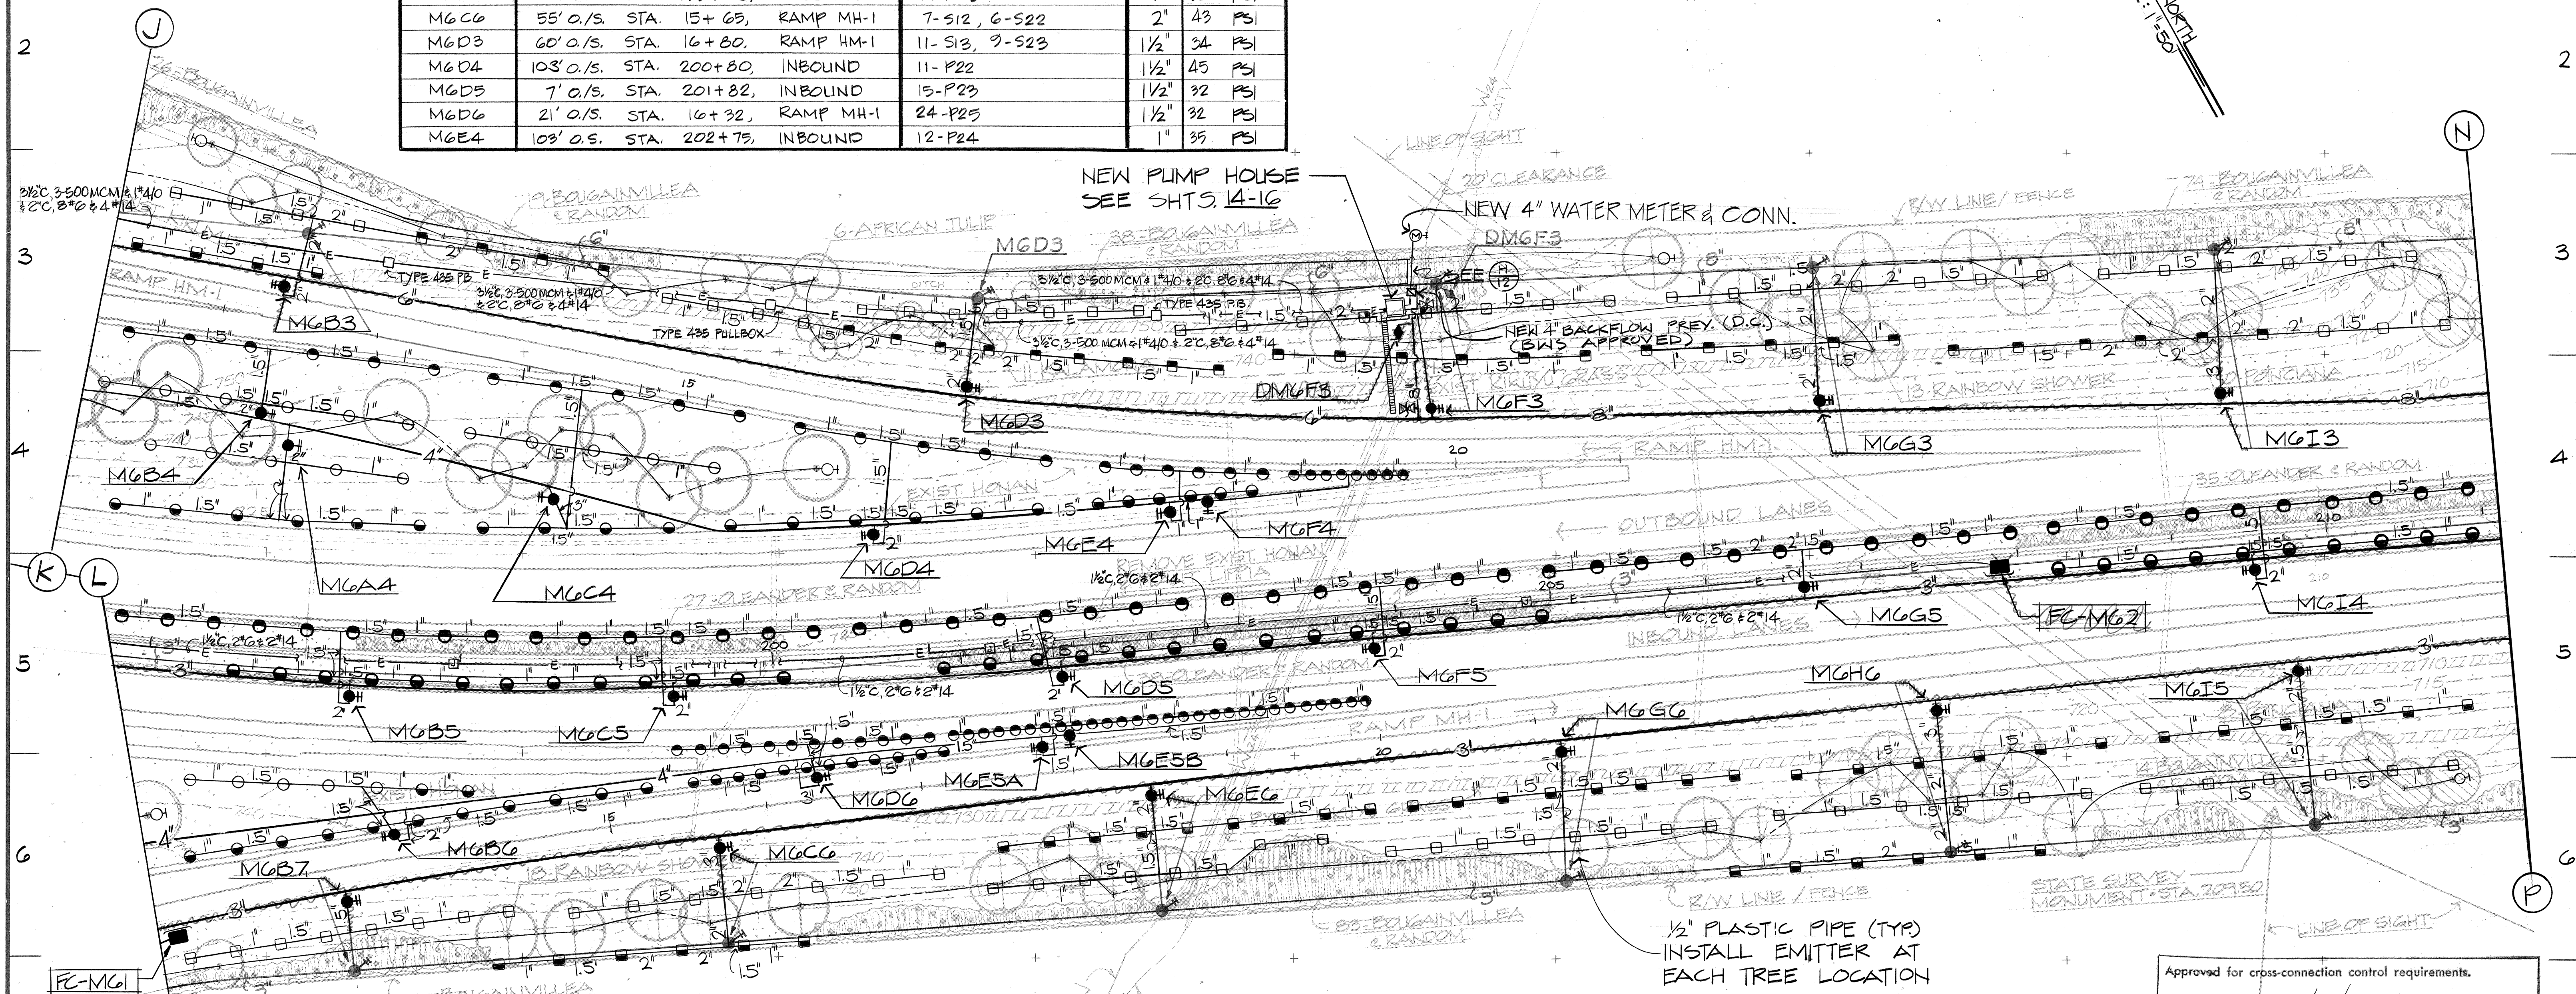

BANK NO.	LOCATION	HEAD (NO.-TYPE)
M6E5A	36' O/S. STA. 202+80, INBOUND	14-P26
M6E5B	36' O/S. STA. 203+20, INBOUND	11-P26
M6E6	44' O/S. STA. 18+50, RAMP MH-1	8-S13, 9-S23
M6F3	68' O/S. STA. 19+80, RAMP HM-1	6-S12, 8-S22
M6F4	6' O/S. STA. 19+30, RAMP HM-1	8-P26
M6F5	7' O/S. STA. 204+00, INBOUND	14-P23
M6G3	13' O/S. STA. 21+33, RAMP HM-1	7-S12, 5-S22
M6G5	7' O/S. STA. 206+70, INBOUND	11-P23
M6G6	107' O/S. STA. 199+97, INBOUND	8-S13, 8-S23
M6H6	108' O/S. STA. 207+50, INBOUND	6-S12, 12-S22
M6I3	150' O/S. STA. 209+50, INBOUND	9-S12, 6-S22
M6I4	7' O/S. STA. 209+68, INBOUND	20-P23
M6I5	105' O/S. STA. 209+84, INBOUND	6-S12, 6-S22


BANK NO.	CONTROL VLV
SIZE	PRESS
M6E5A	1" 17 PSI
M6E5B	1" 31 PSI
M6E6	1 1/2" 33 PSI
M6F3	2" 43 PSI
M6F4	1" 20 PSI
M6F5	1" 32 PSI
M6G3	2" 45 PSI
M6G5	1" 33 PSI
M6G6	1 1/2" 33 PSI
M6H6	2" 45 PSI
M6I3	2" 43 PSI
M6I4	1 1/2" 33 PSI
M6I5	2" 45 PSI

Approved for cross-connection control requirements.
 Board of Water Supply
 Date 10-8-76

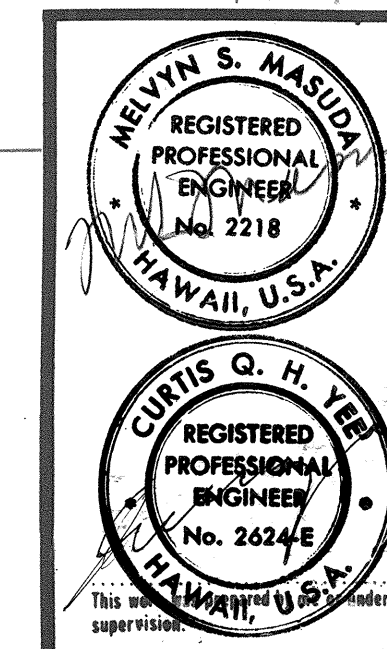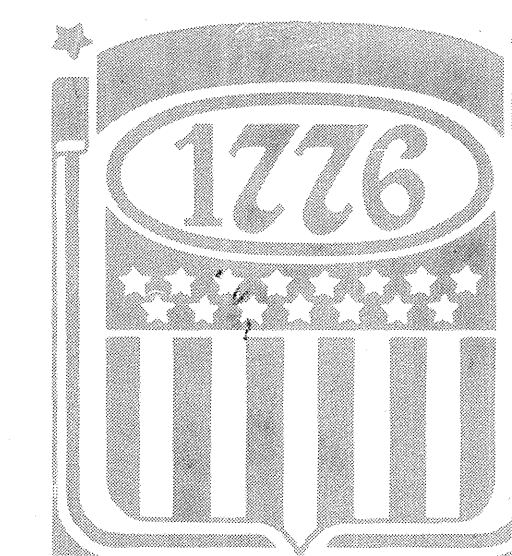



STATE OF HAWAII
 DEPARTMENT OF TRANSPORTATION
 HIGHWAYS DIVISION
 PROJECT NO. I-H2-1(13):4
MILILANI INTERCHANGE
SPRINKLER PLAN
AREA "M-6"
 SHEET No. 9 OF 25 SHEETS

FED. ROAD DIST. NO.	STATE	FED. AID PROJ. NO.	FISCAL YEAR	SHEET NO.	TOTAL SHEETS
HAWAII	HAW.	I-H2-1(13):4	1977	19	34

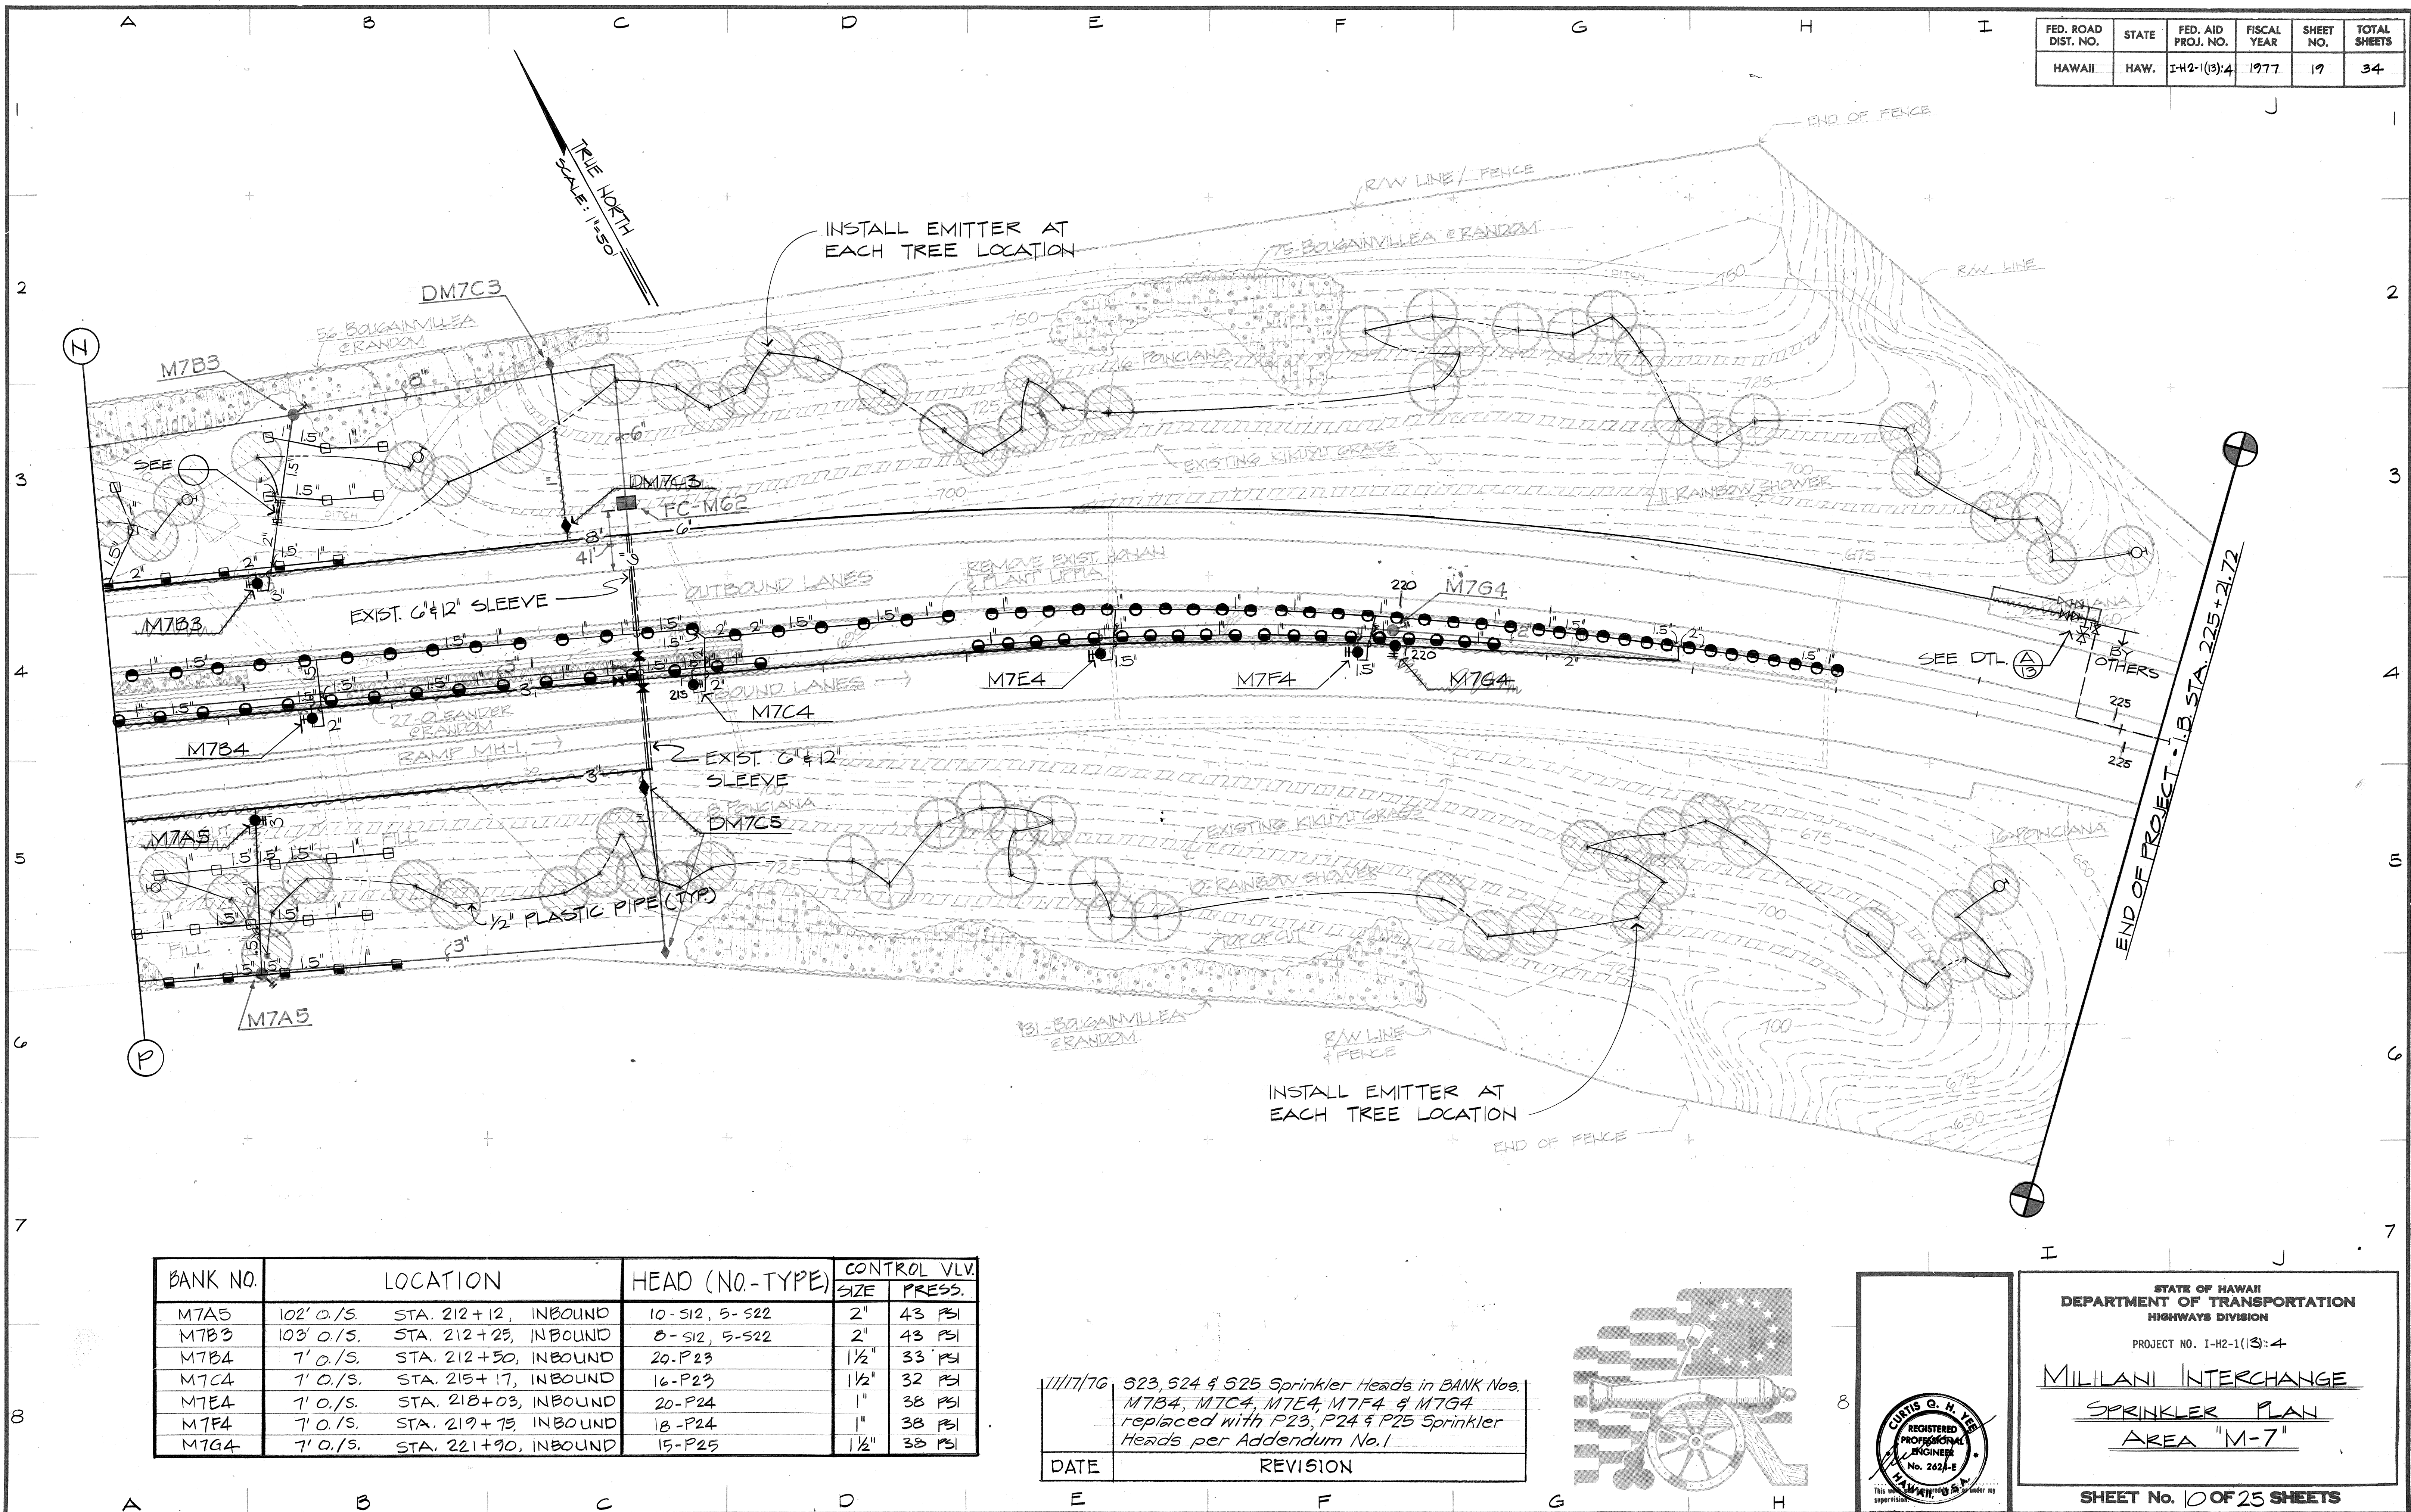

BANK NO.	LOCATION	HEAD (NO.-TYPE)	CONTROL VLV.	
			SIZE	PRESS.
M7A5	102' O/S. STA. 212+12, INBOUND	10-S12, 5-S22	2"	43 PSI
M7B3	103' O/S. STA. 212+23, INBOUND	8-S12, 5-S22	2"	43 PSI
M7B4	7' O/S. STA. 212+50, INBOUND	20-P23	1 1/2"	33 PSI
M7C4	7' O/S. STA. 215+17, INBOUND	16-P23	1 1/2"	32 PSI
M7E4	7' O/S. STA. 218+03, INBOUND	20-P24	1"	38 PSI
M7F4	7' O/S. STA. 219+75, INBOUND	18-P24	1"	38 PSI
M7G4	7' O/S. STA. 221+90, INBOUND	15-P25	1 1/2"	38 PSI

11/17/76	523, 524 & 525 Sprinkler Heads in BANK Nos. M7B4, M7C4, M7E4, M7F4 & M7G4 replaced with P23, P24 & P25 Sprinkler Heads per Addendum No.1
DATE	REVISION

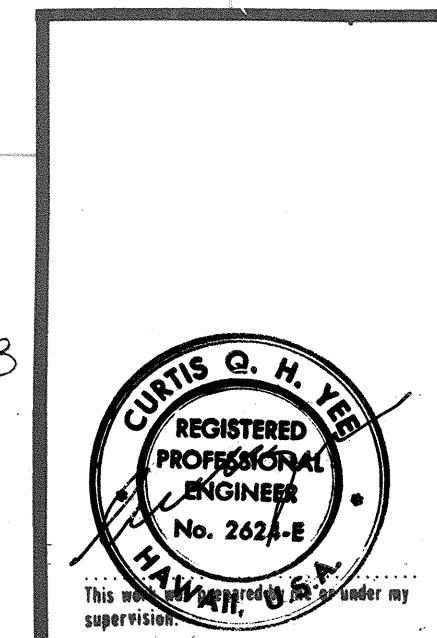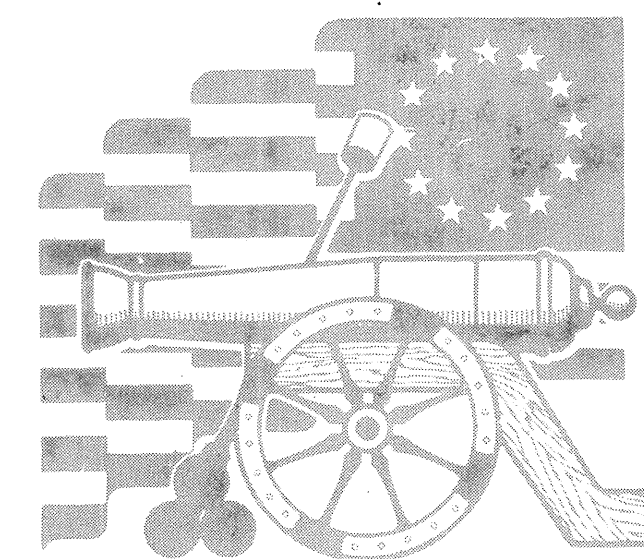


STATE OF HAWAII
DEPARTMENT OF TRANSPORTATION
HIGHWAYS DIVISION
PROJECT NO. I-H2-1(13):4
MILILANI INTERCHANGE
SPRINKLER PLAN
AREA "M-7"
SHEET No. 10 OF 25 SHEETS

DATE	11/17/76
DESIGNED BY	...
DRAWN BY	...
CHECKED BY	...
NOTED BY	...
APPROVED BY	...


FED. ROAD DIST. NO.	STATE	FED. AID PROJ. NO.	FISCAL YEAR	SHEET NO.	TOTAL SHEETS
HAWAII	HAW.	I-42-1(13)-4	1977	20	34

NOTE: TEES, GATE VALVE, BOX, COVER, UNIONS, NIPPLES, ADAPTERS, CRUSHED ROCK, ETC. SHALL BE CONSIDERED INCIDENTAL TO THE VALVE INSTALLATION AND SHALL NOT BE MEASURED OR PAID FOR SEPARATELY.

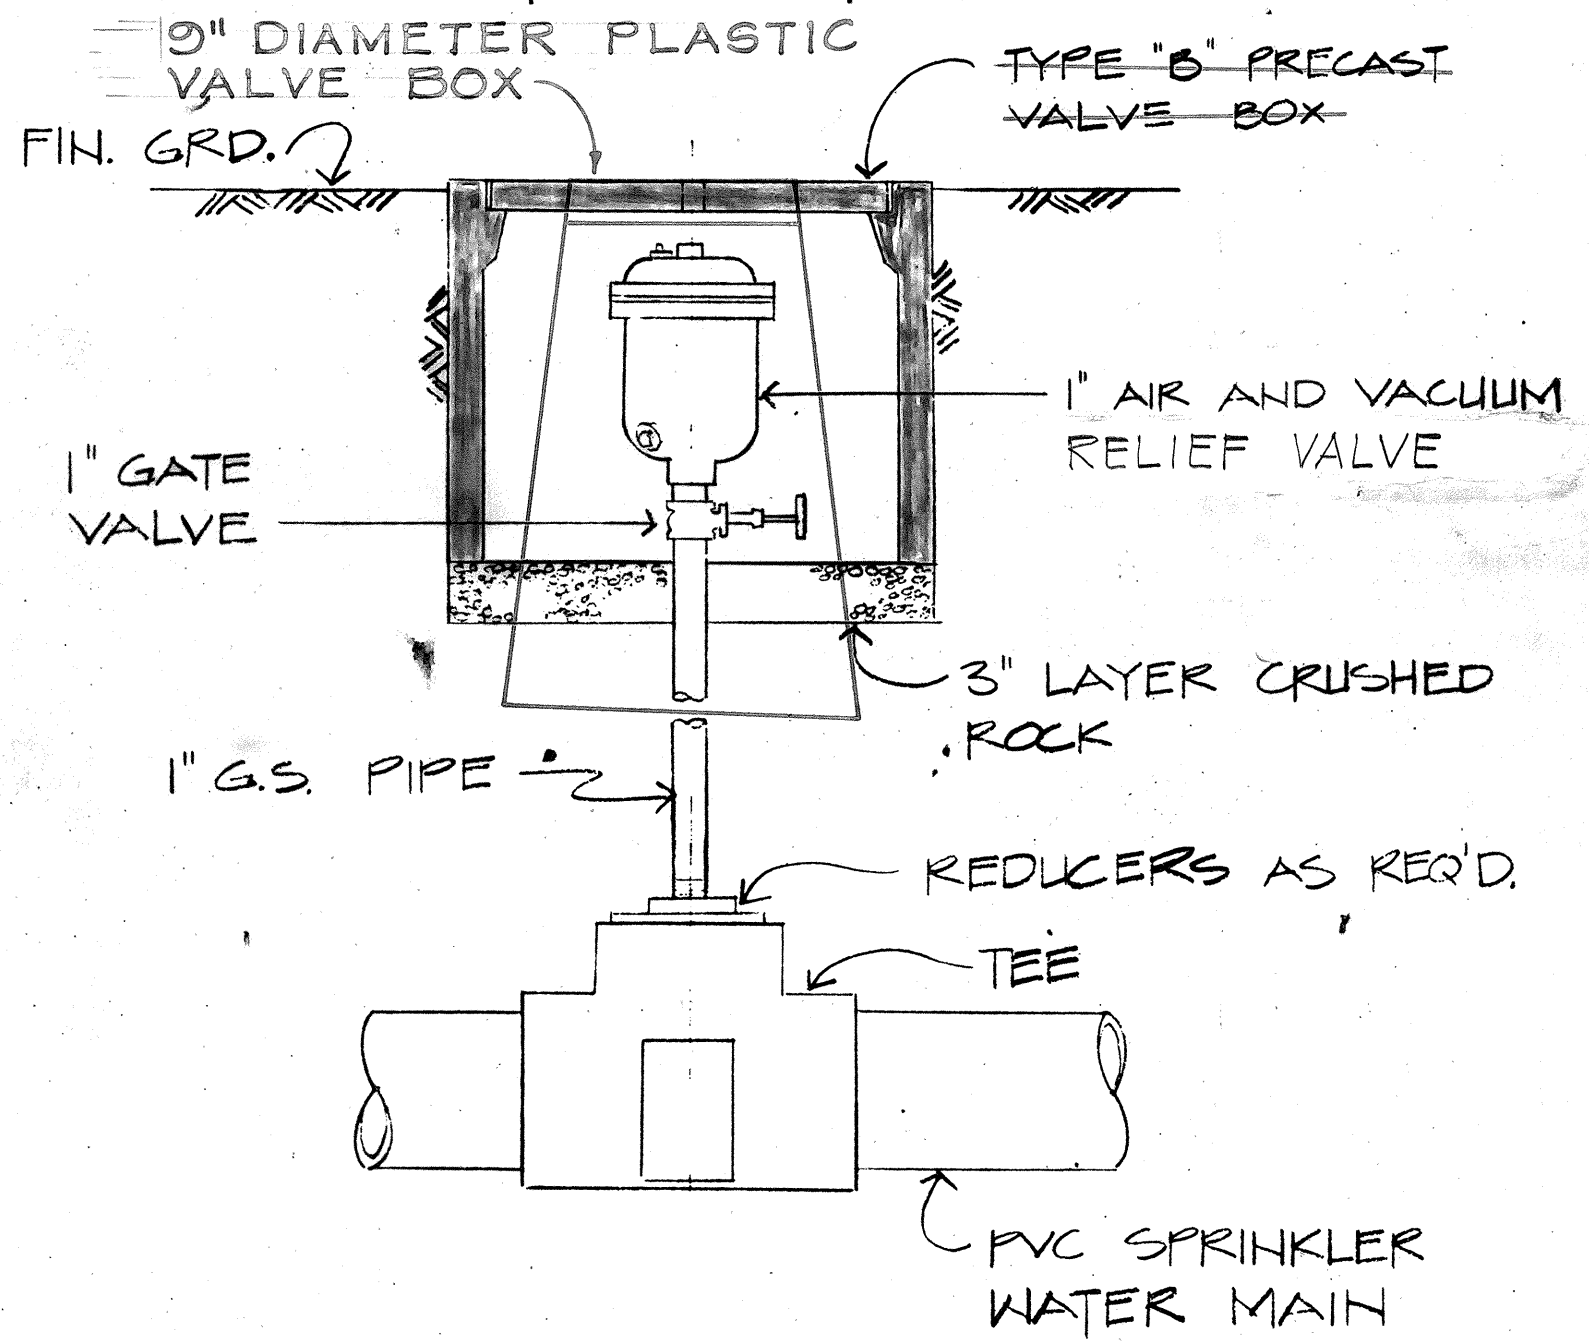


A TYP. AIR & VACUUM RELIEF VALVE
N.T.S.



- NOTE:
1. THE SPRINKLER HEAD WITH THE REQUIRED RISER, SWING JOINT AND ANTI-DRAIN CHECK VALVE SHALL BE MEASURED AND PAID FOR AS A UNIT.
 2. SWING JOINT ASSEMBLIES SHALL BE INSTALLED FOR ALL POP-UP SPRINKLER HEADS.
 3. UNLESS OTHERWISE INDICATED, ANTI-DRAIN CHECK VALVES SHALL BE INSTALLED ON ALL SPRINKLER HEADS OF RADII 20, 30 AND 40 FEET.

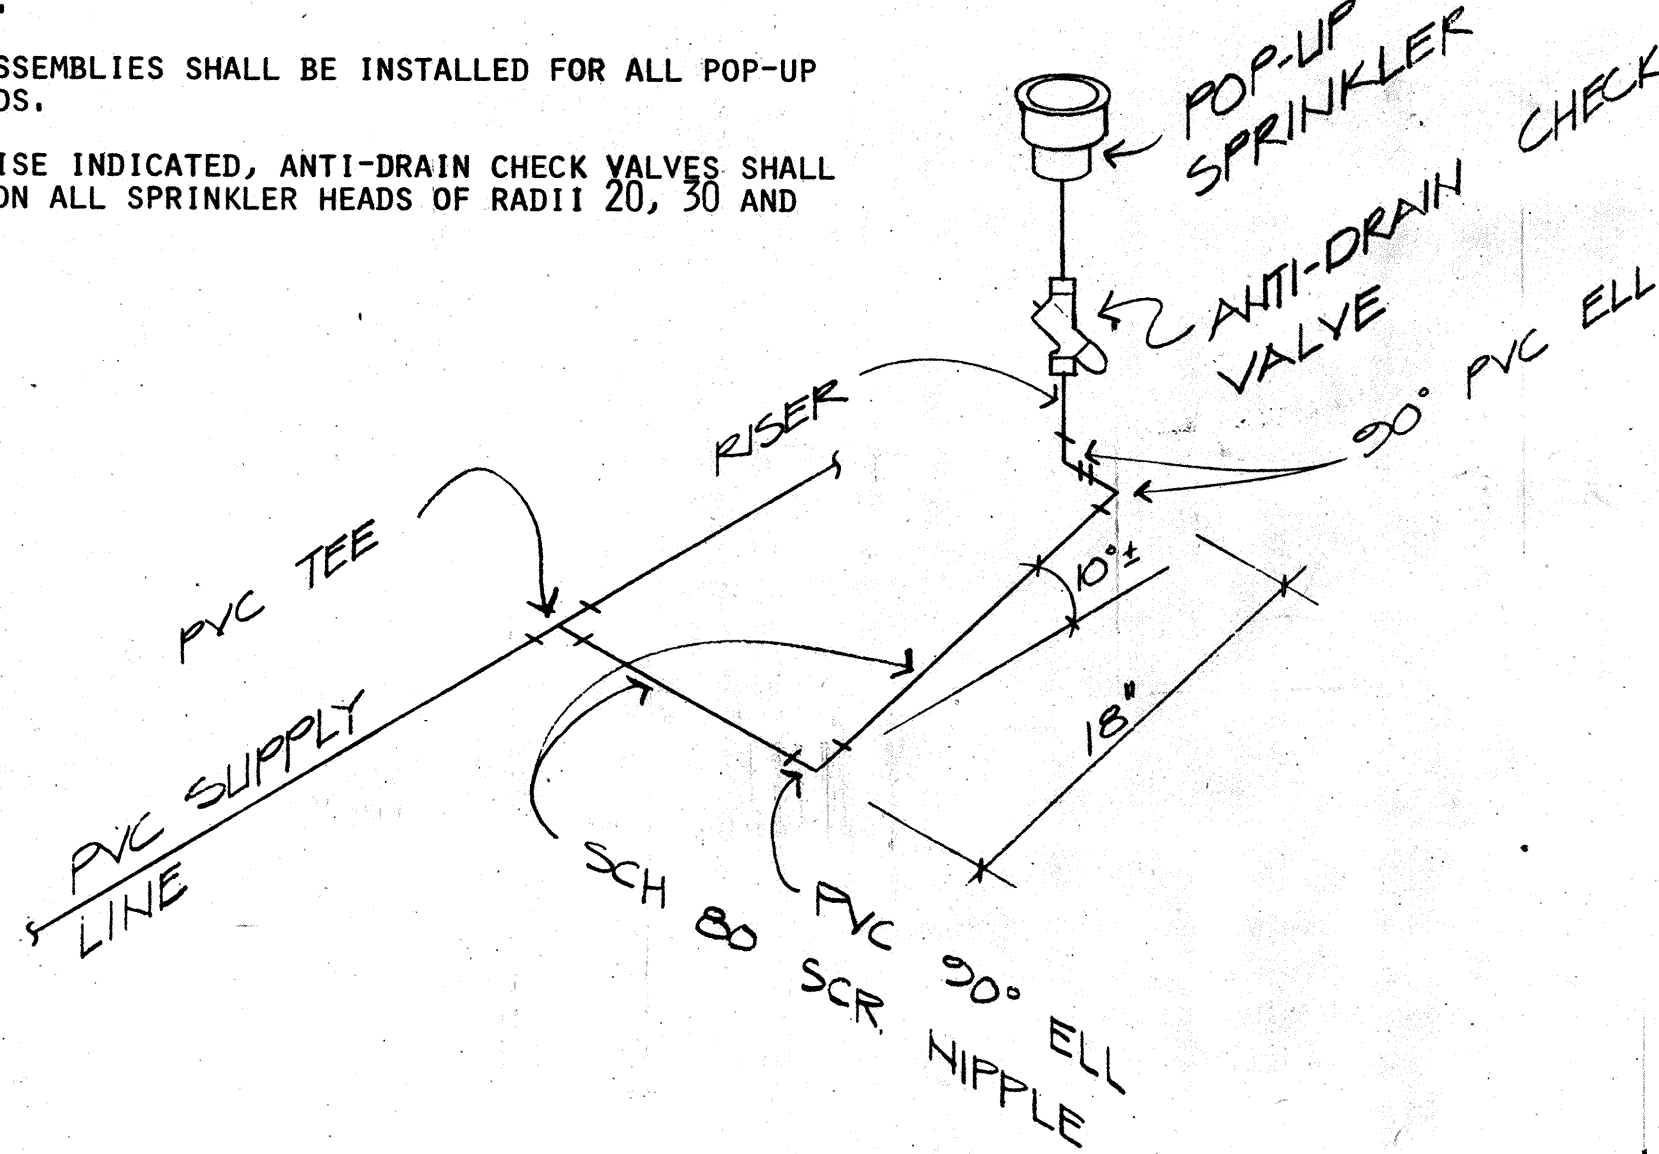


G ISOMETRIC-SWING JOINT ASSEMBLY
N.T.S.

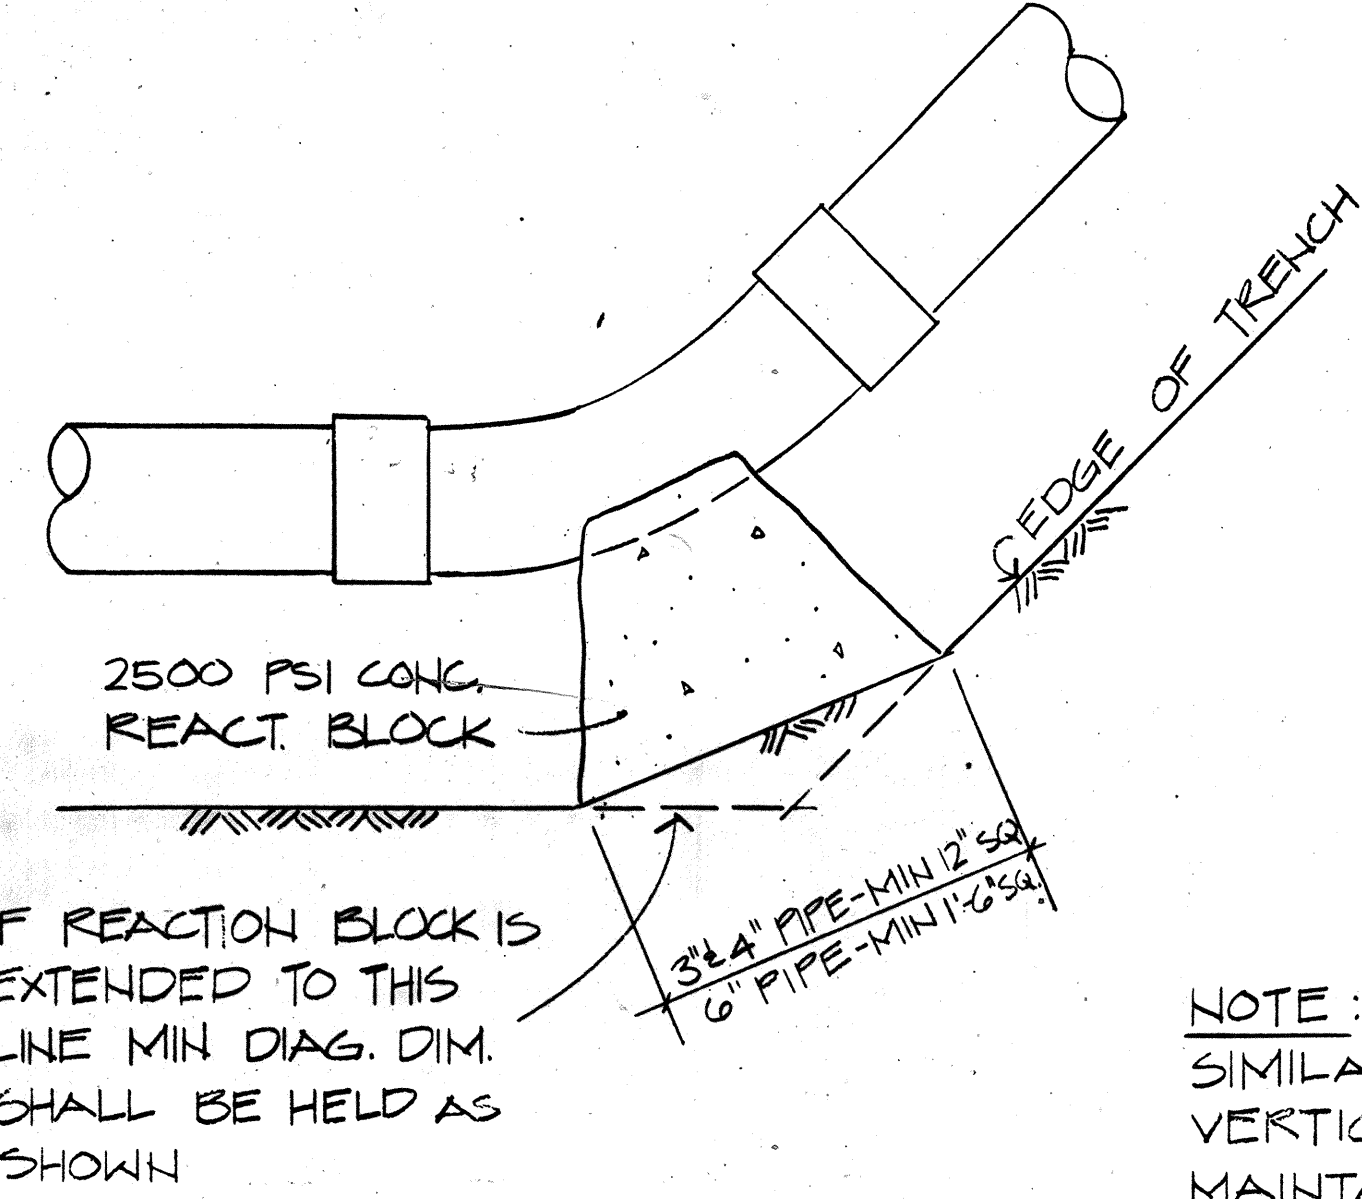


B TYP. REACTION BLOCK @ 45° BEND
N.T.S.

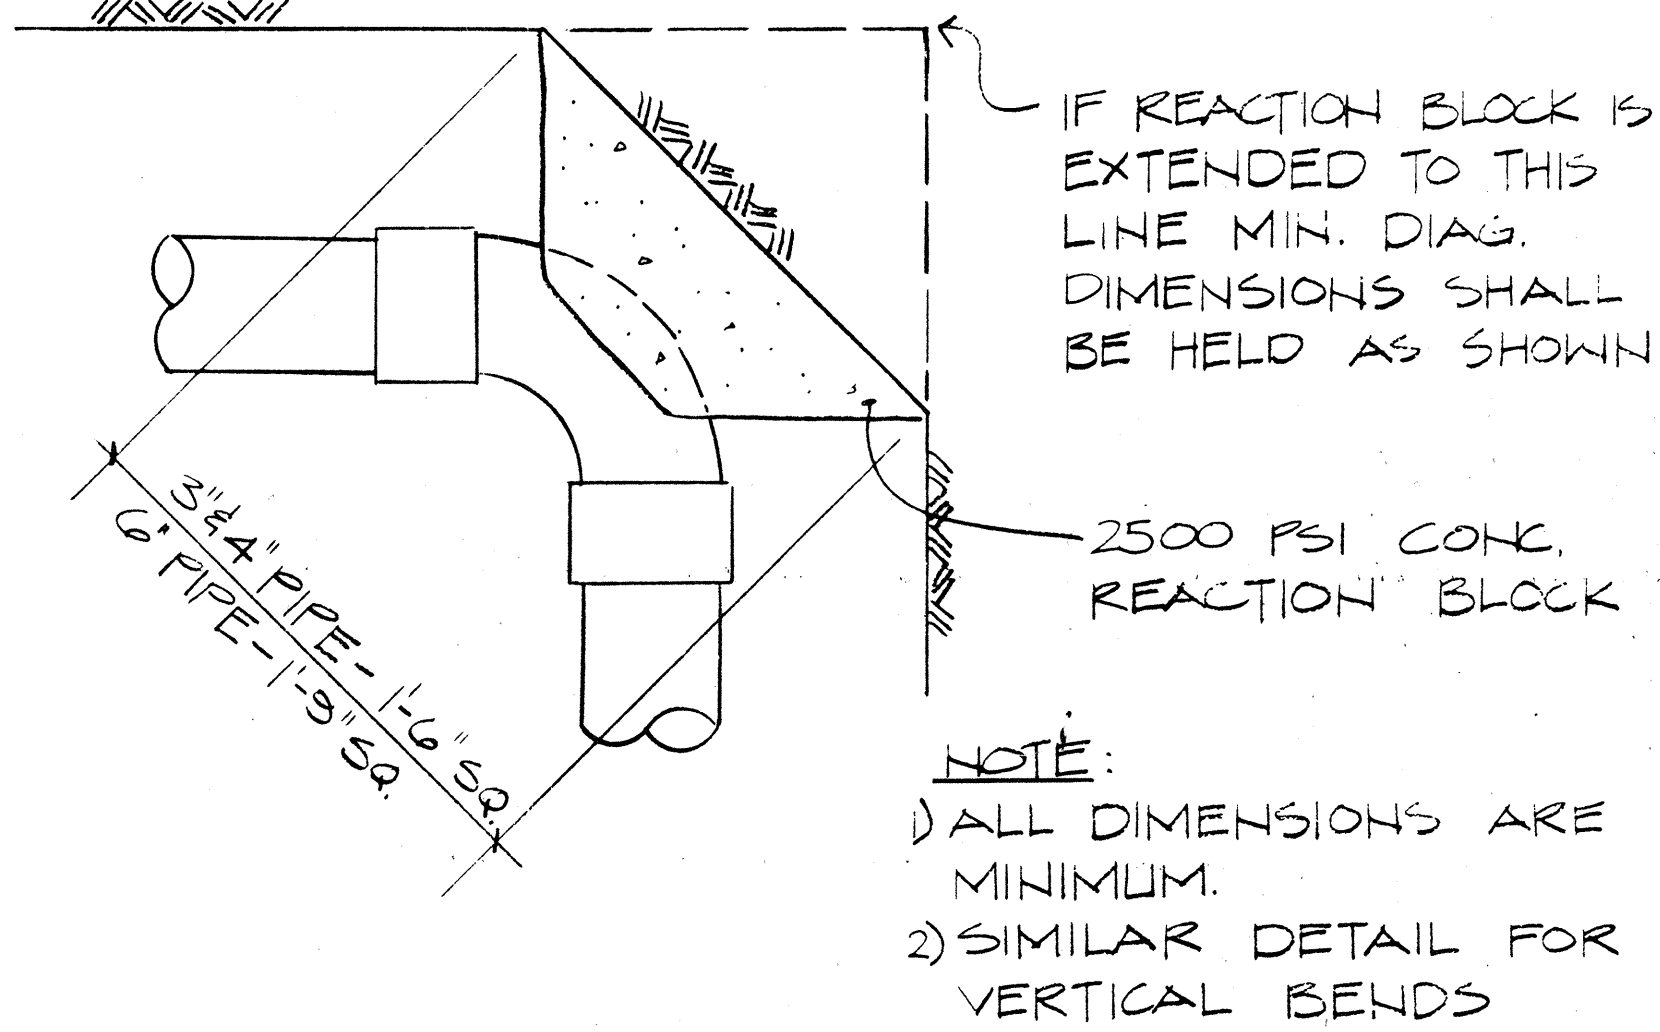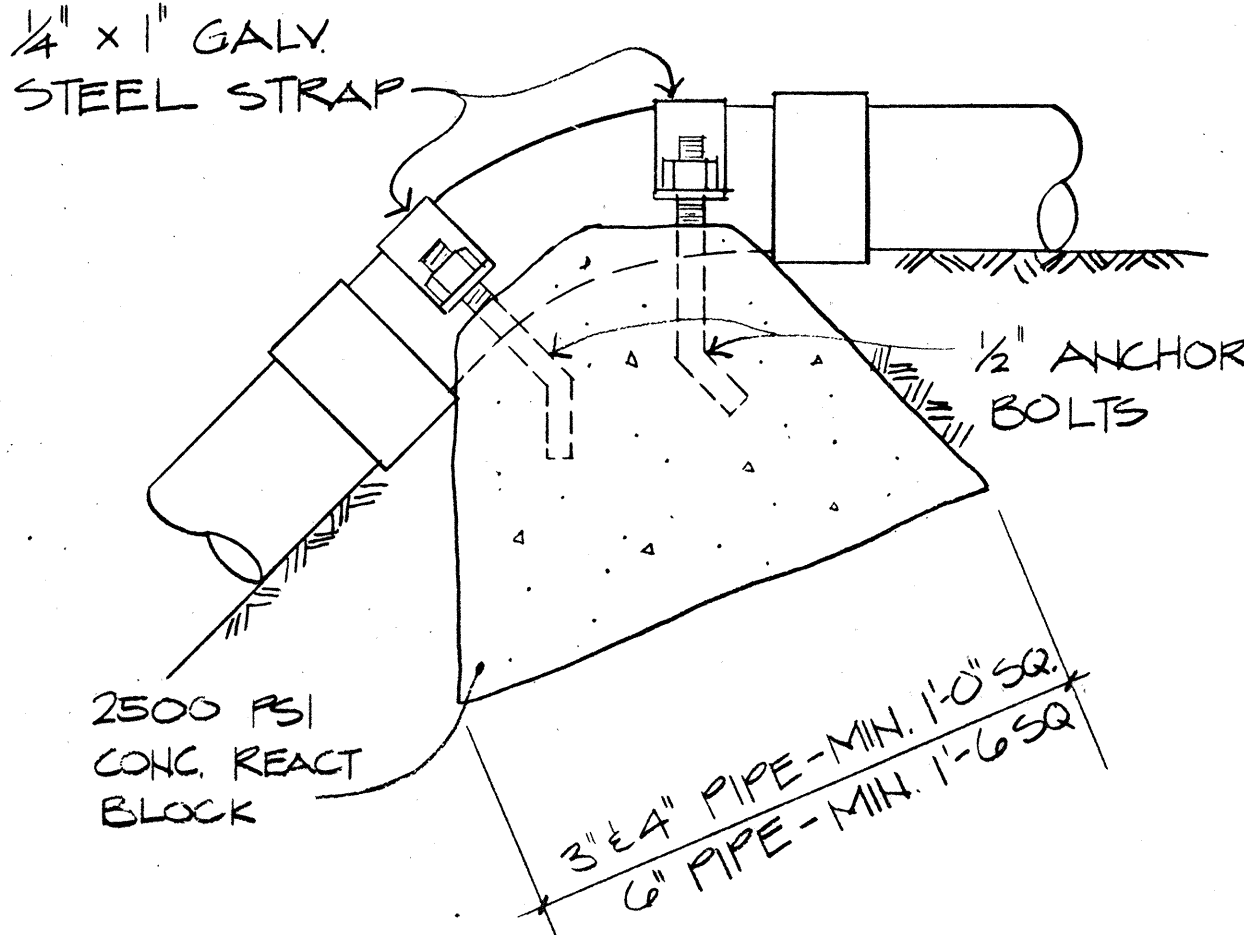

C TYP. REACTION BLOCK @ ELL
N.T.S.

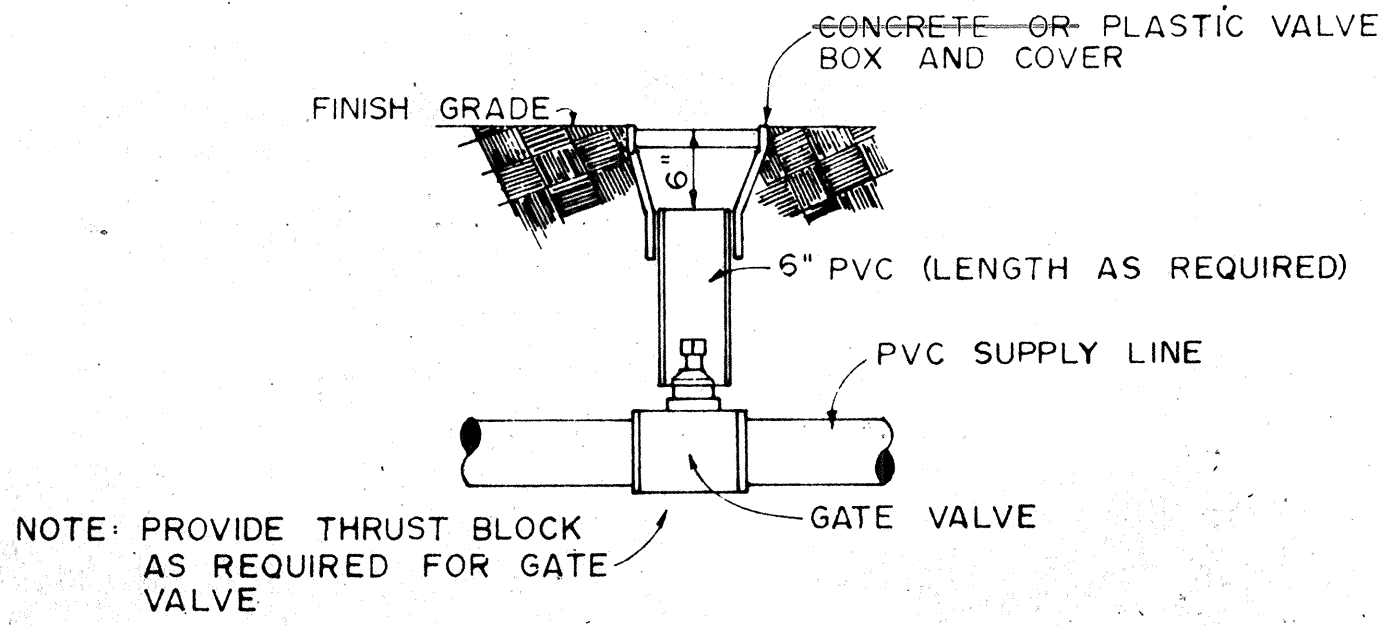

E GATE VALVE INSTALLATION
N.T.S.

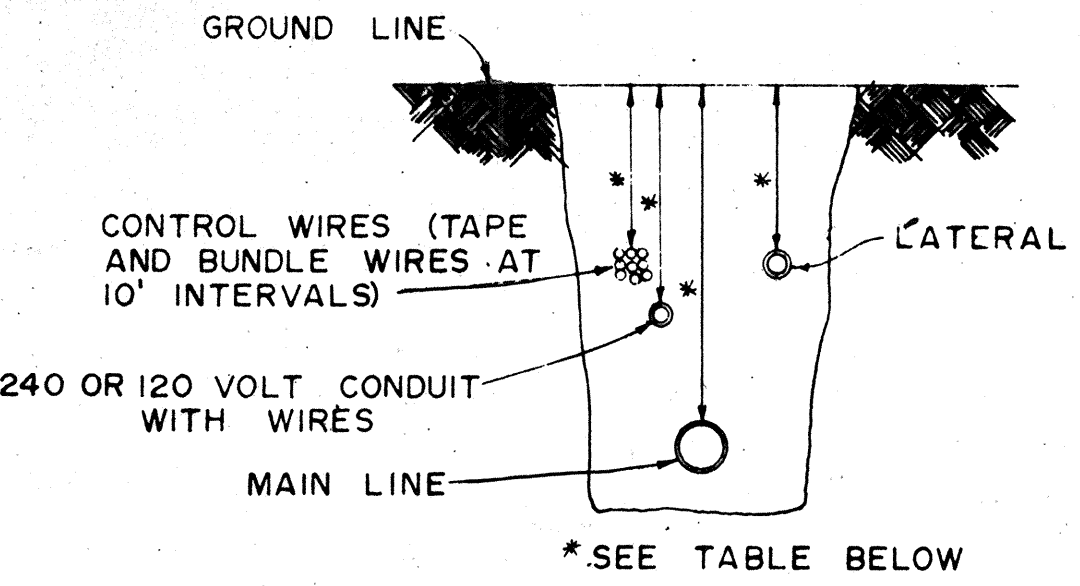



	* MINIMUM COVER
SPRINKLER LATERALS	18"
SPRINKLER MAINS	
4" AND SMALLER	24"
6"	30"
ELECTRICAL CONDUITS	24"
CONTROL WIRES	24"

F TRENCH DETAIL
N.T.S.

D AUTO. SPRINKLER CONTROL VALVE
N.T.S.

DATE	11/17/76
DESIGNED BY	REVISOR
QUANTITY BY	DATE
CHECKED BY	REVISION
NOTES	
NO.	

11/17/76	Revised terminology and title of value for Detail
DATE	REVISION

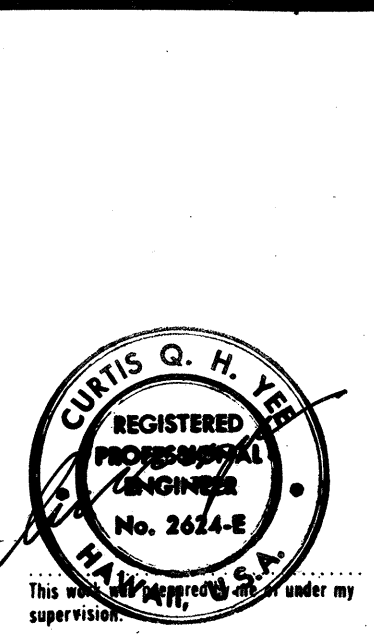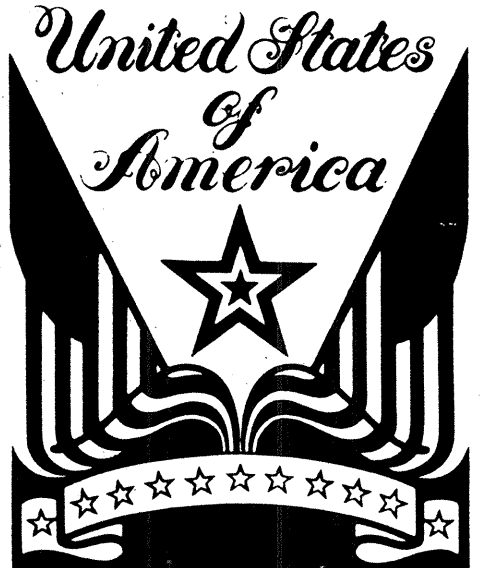


STATE OF HAWAII
DEPARTMENT OF TRANSPORTATION
HIGHWAYS DIVISION

PROJECT NO. I-42-1(13)-4

MILILANI INTERCHANGE
PIPING DETAIL


SHEET No. 11 OF 25 SHEETS

FED. ROAD DIST. NO.	STATE	FED. AID PROJ. NO.	FISCAL YEAR	SHEET NO.	TOTAL SHEETS
HAWAII	HAW.	142-1(13)4	1977	21	34

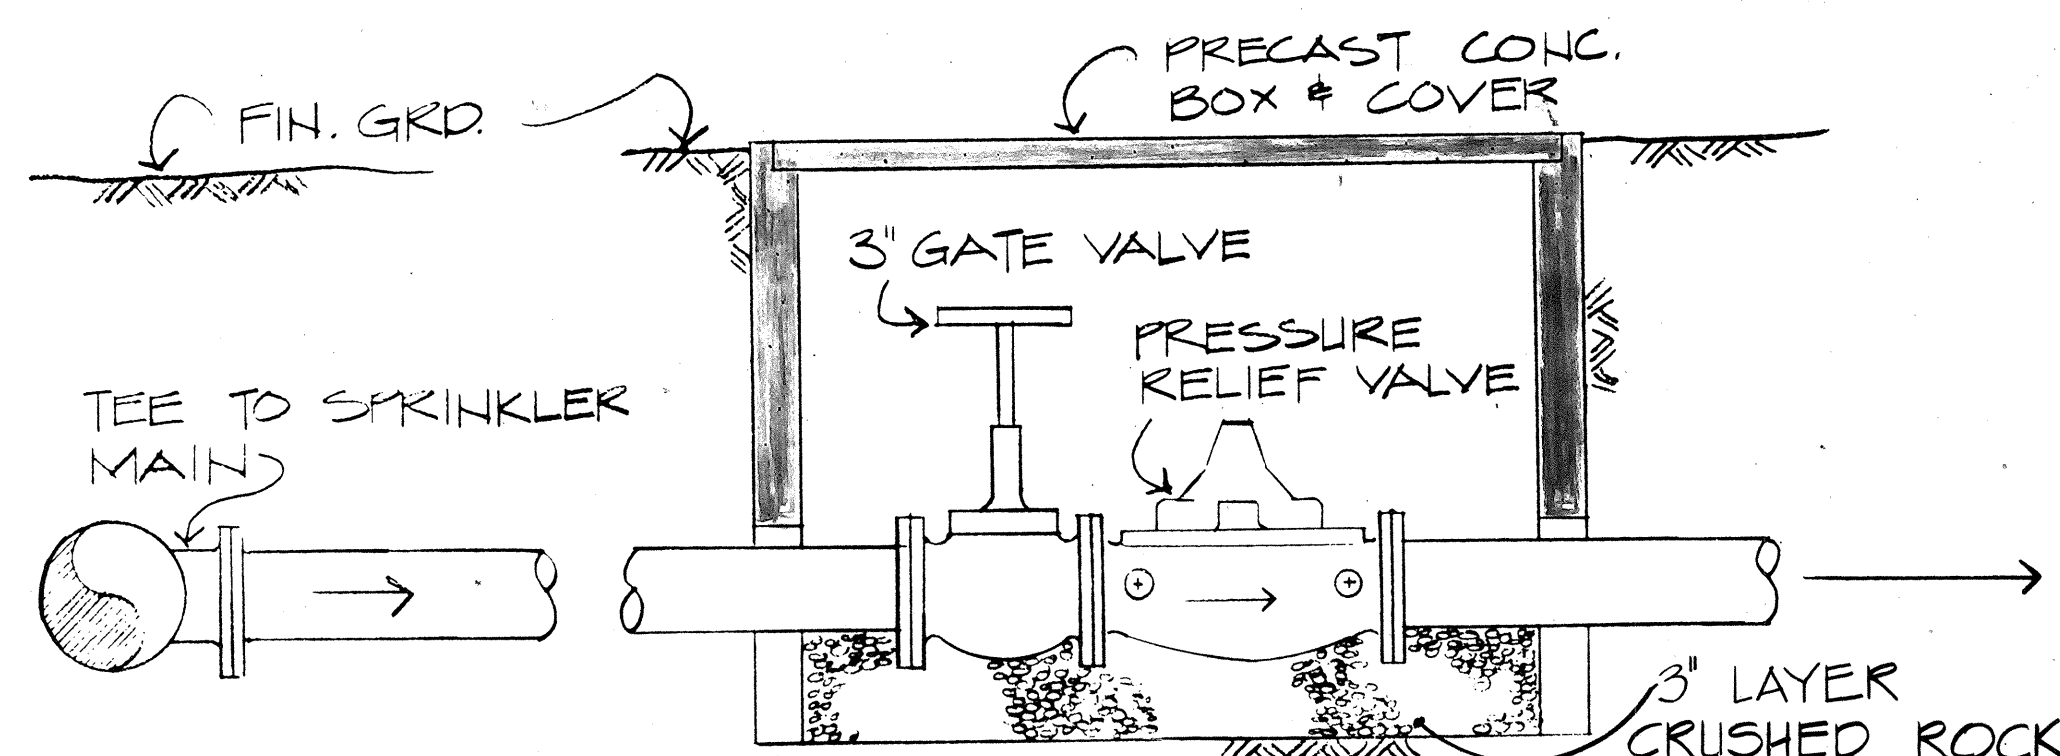

NOTE: BOX, COVER, UNIONS, NIPPLES, ADAPTERS, CRUSHED ROCK, ETC. SHALL BE CONSIDERED INCIDENTAL TO THE VALVE INSTALLATION AND SHALL NOT BE MEASURED OR PAID FOR SEPARATELY.


(A) PRESSURE RELIEF VALVE ASSEMBLY
HIS

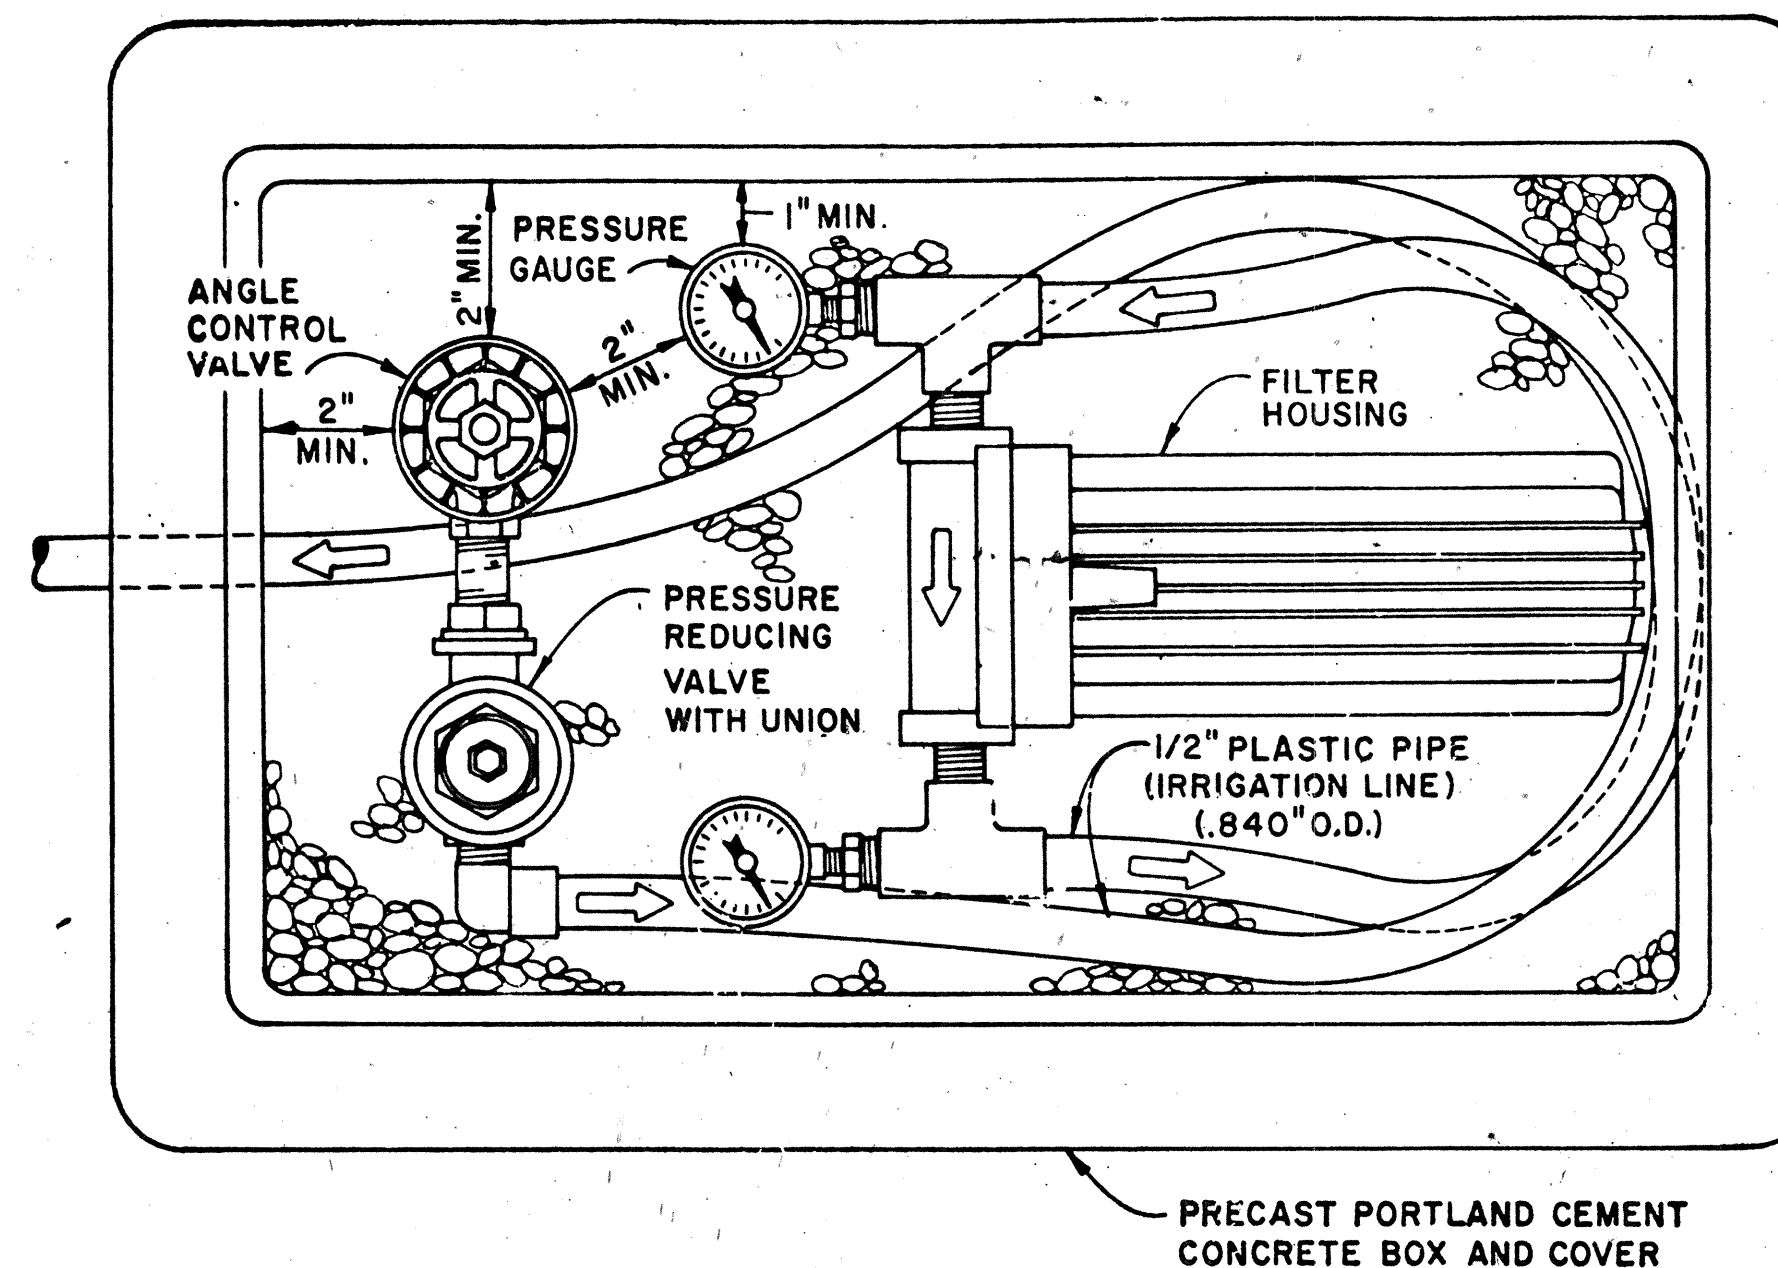


PLAN

(B)
12


VALVE ASSEMBLY UNIT

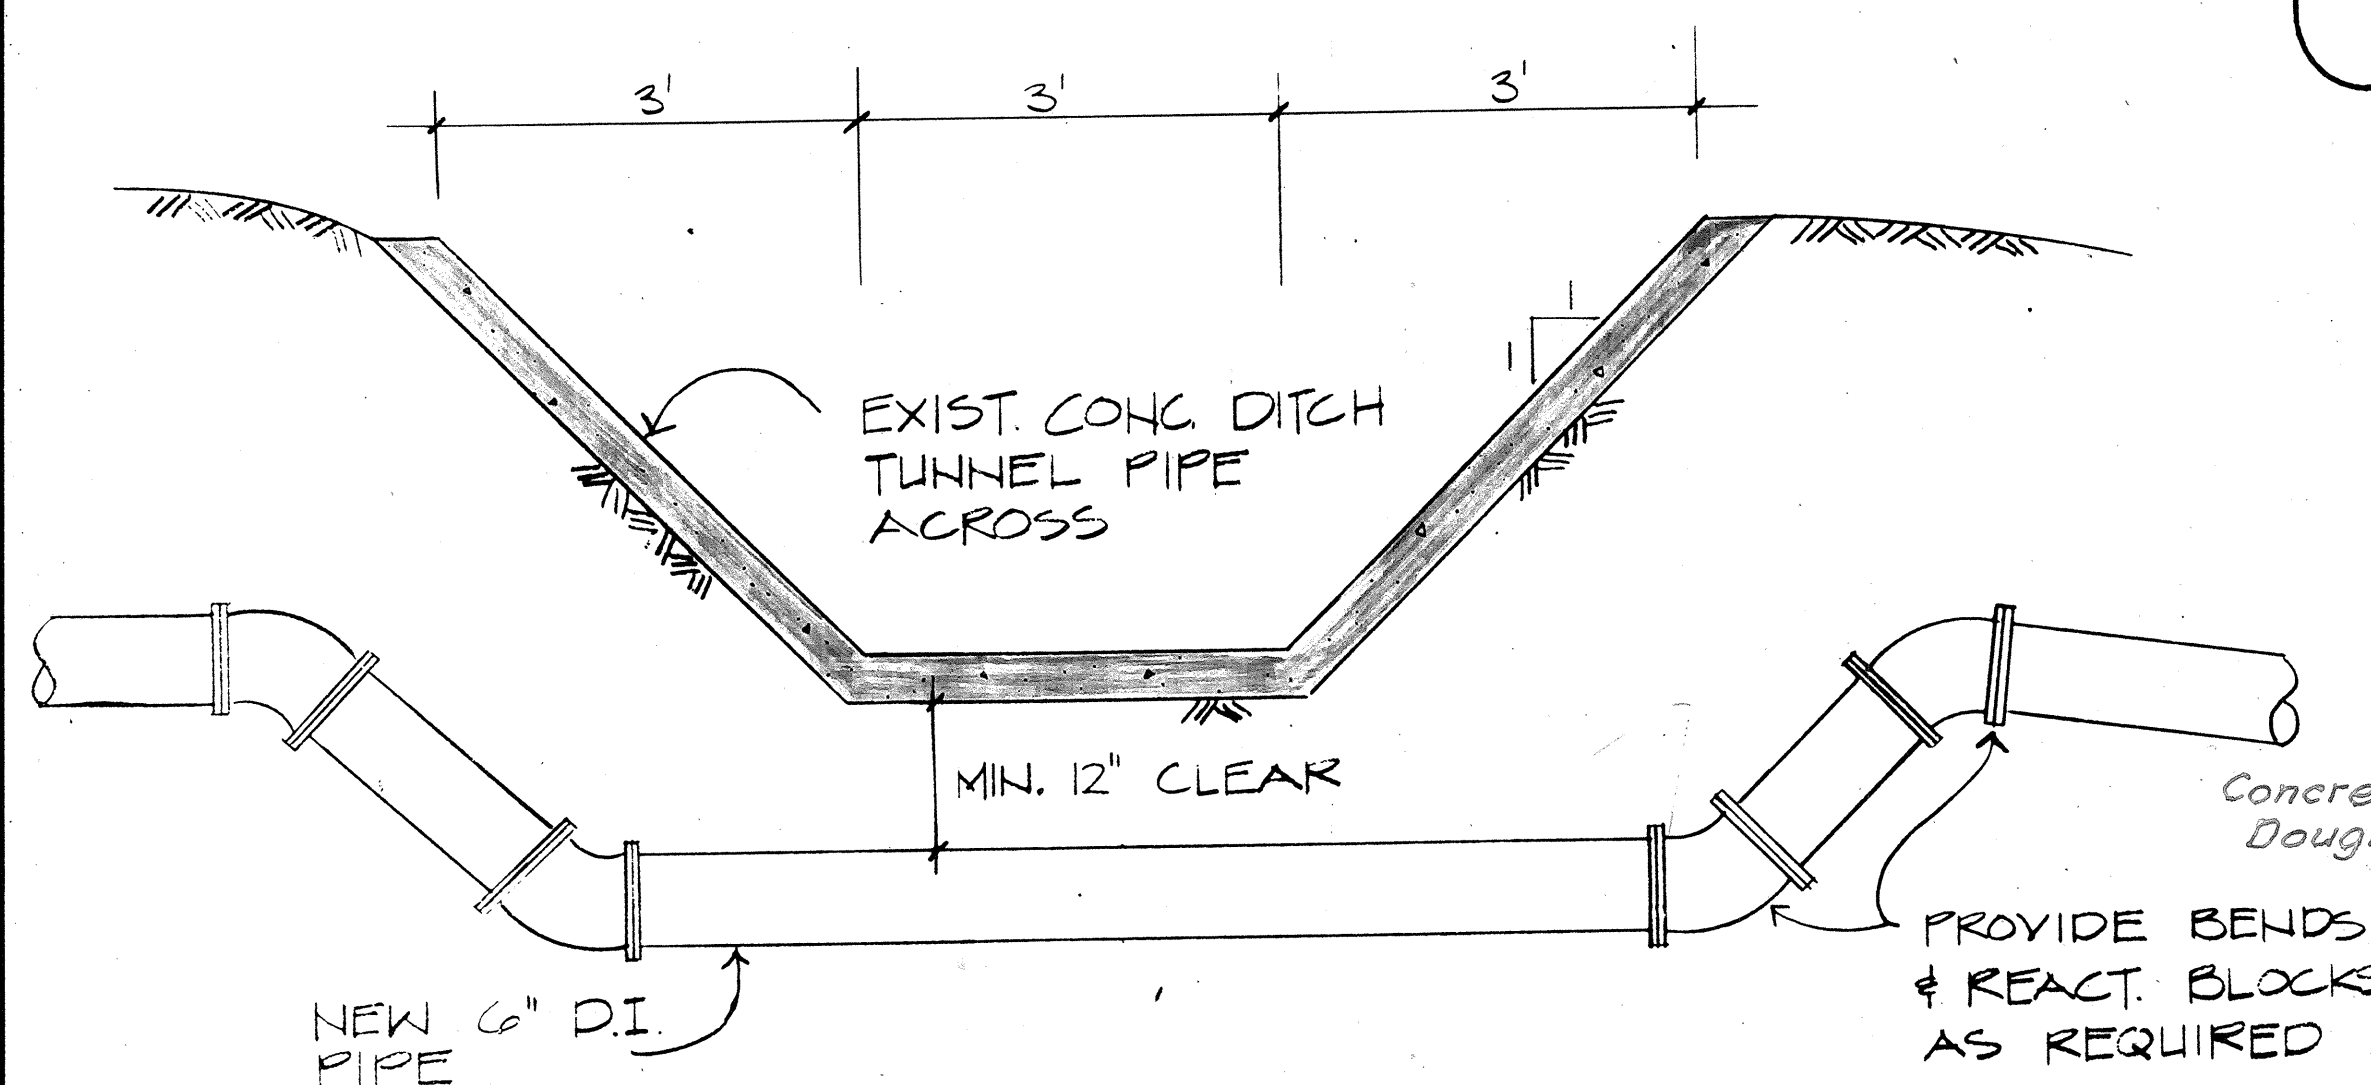


 DETAIL
 SC: $\frac{3}{4}" = 1'-0"$

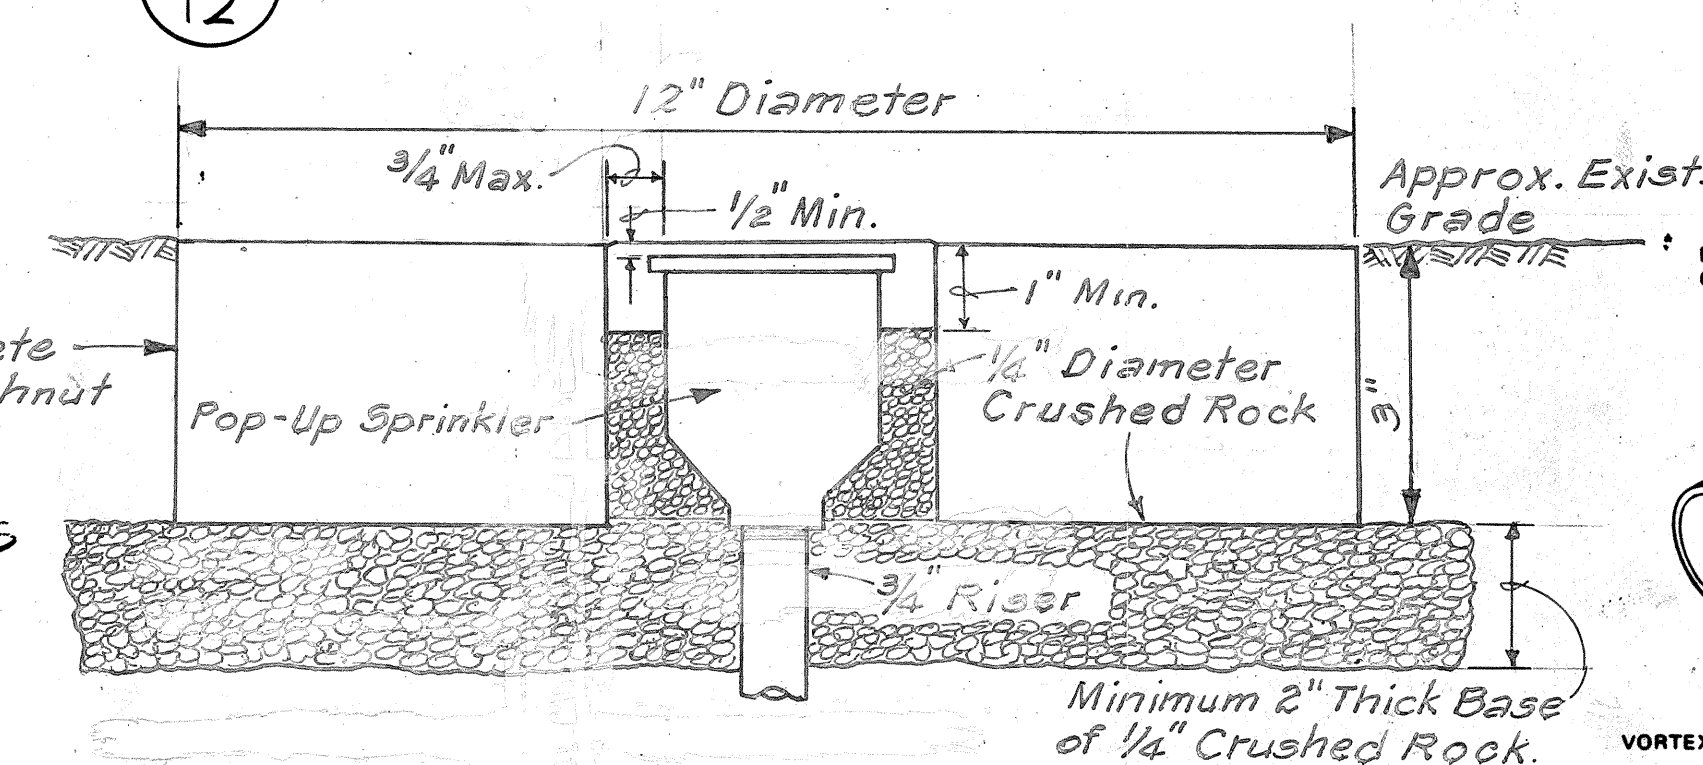

TYPICAL CONCRETE DOUGHNUT DETAILS
ROADWAY MEDIAN @ STA. 138+95 ± TO @ STA. 223+00
C.C.O. NO. 9
N.T.S.

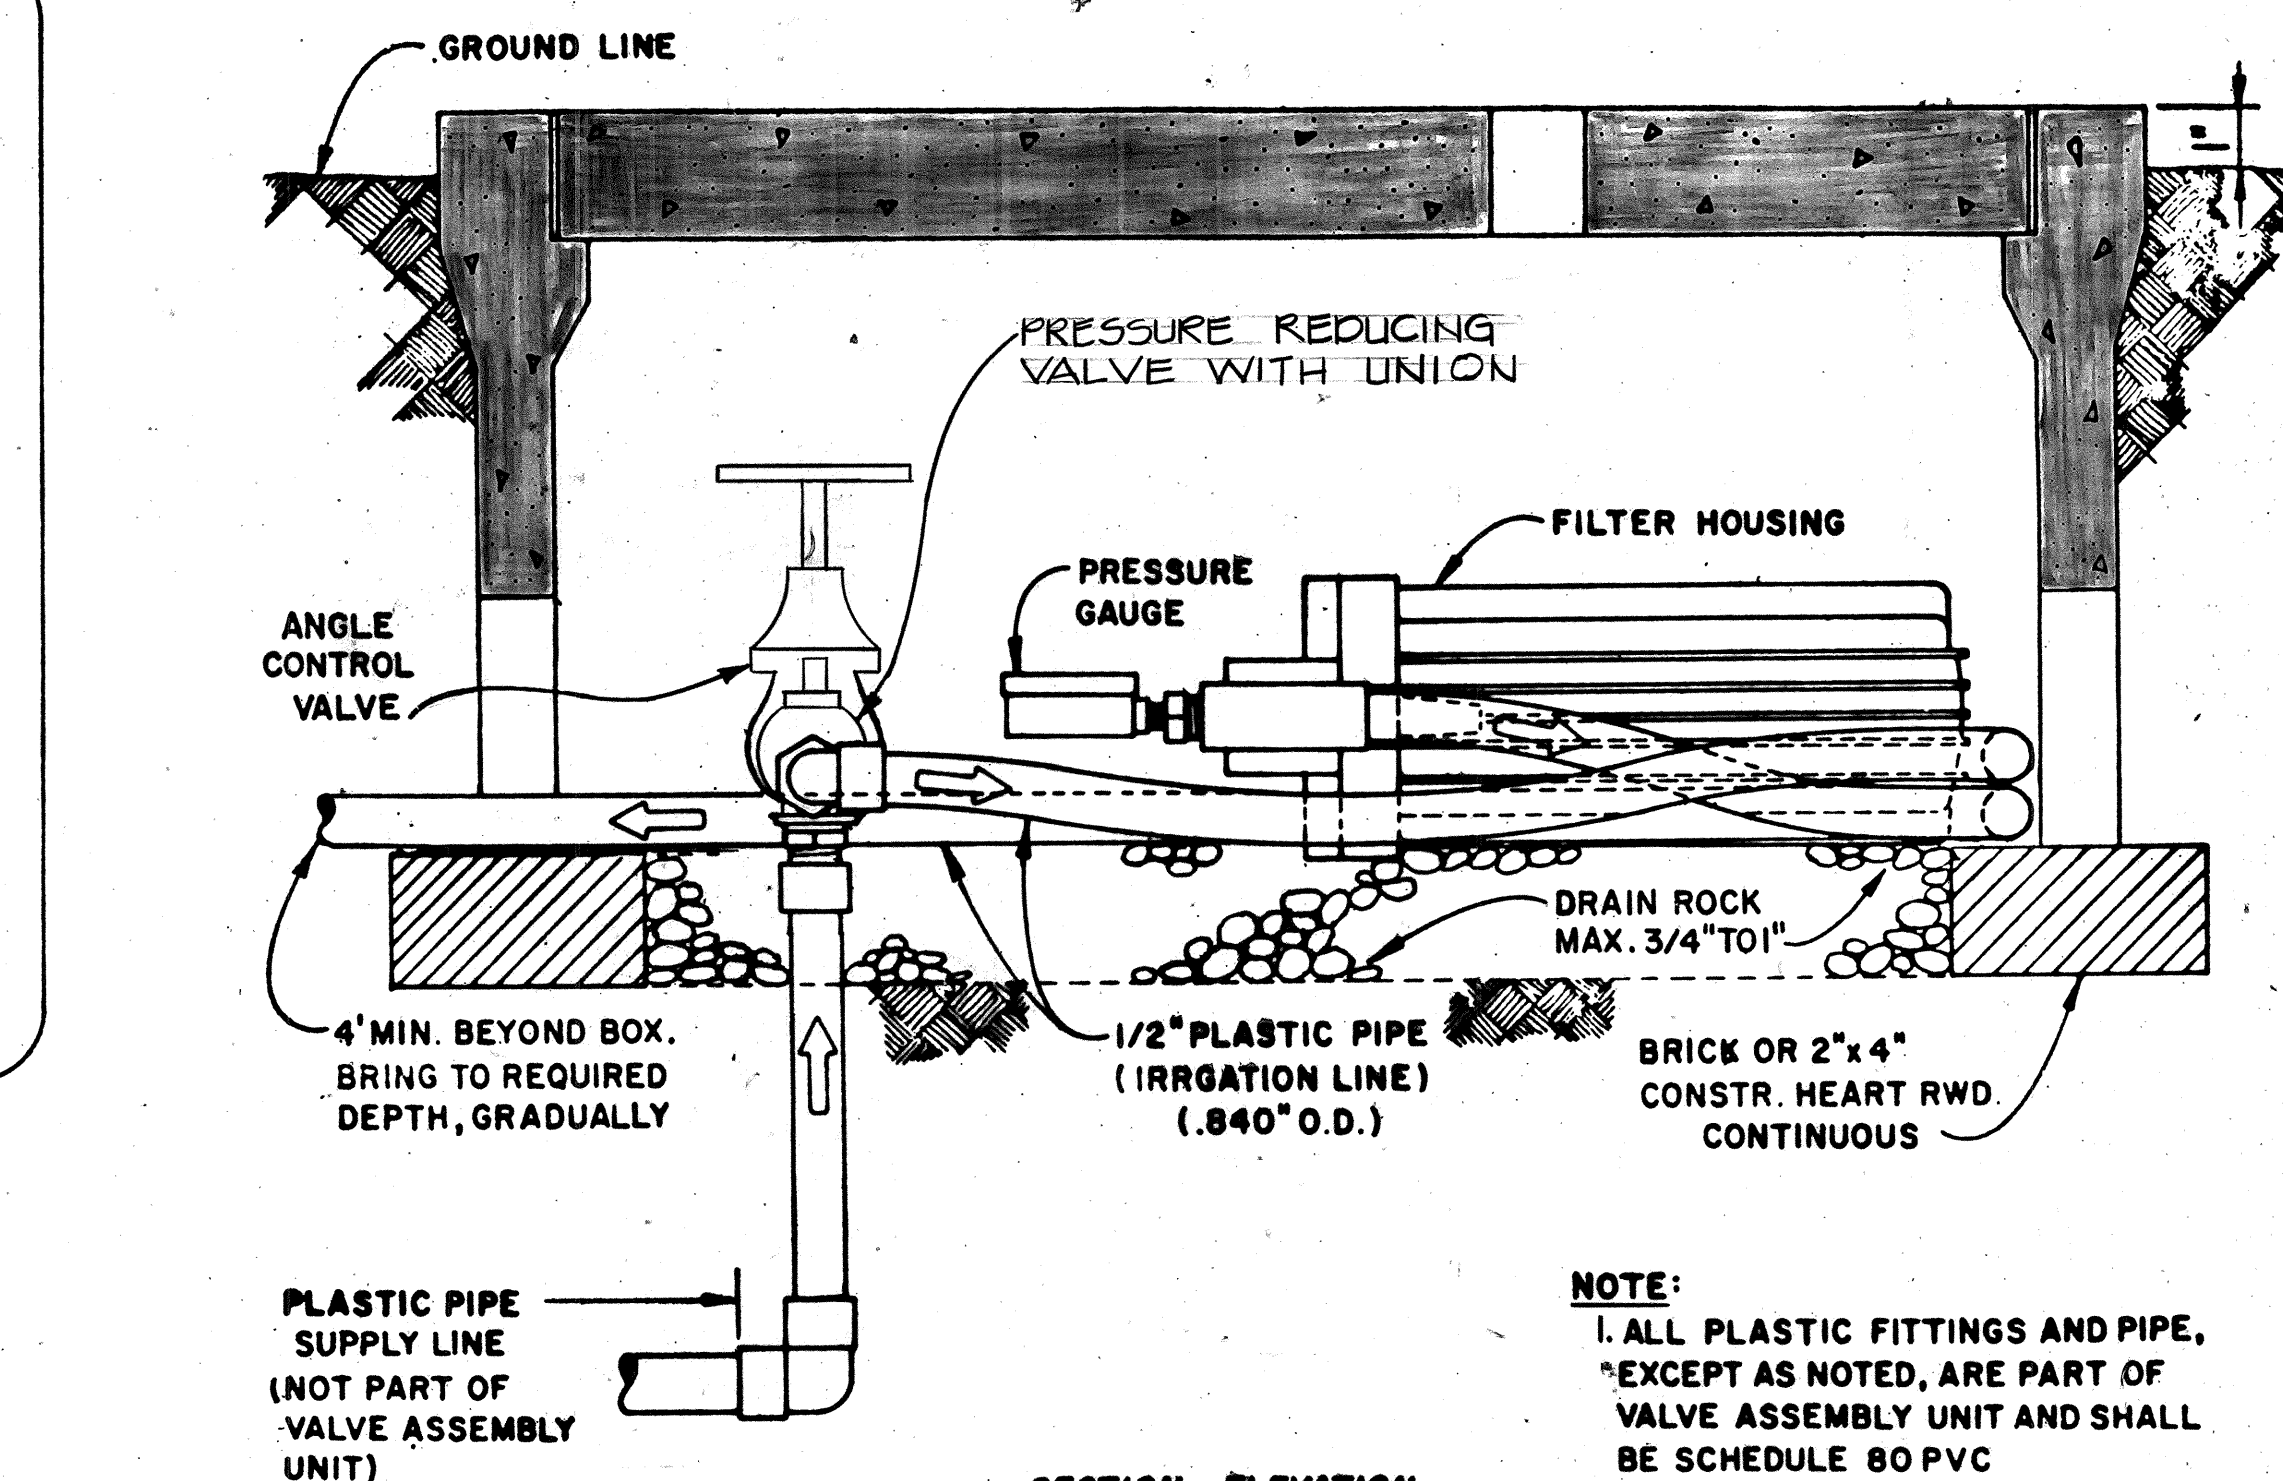


SECTION - ELEVATION


(C)
12

VALVE ASSEMBLY UNIT


NOTE:
1. ALL PLASTIC FITTINGS AND PIPE,
EXCEPT AS NOTED, ARE PART OF
VALVE ASSEMBLY UNIT AND SHALL
BE SCHEDULE 80 PVC
2. BOX, COVER, UNIONS, NIPPLES,
ADAPTERS, CRUSHED ROCK, ETC.
SHALL BE CONSIDER INCIDENTAL
TO THE VALVE INSTALLATION
AND SHALL NOT BE MEASURED
OR PAID FOR SEPARATELY.

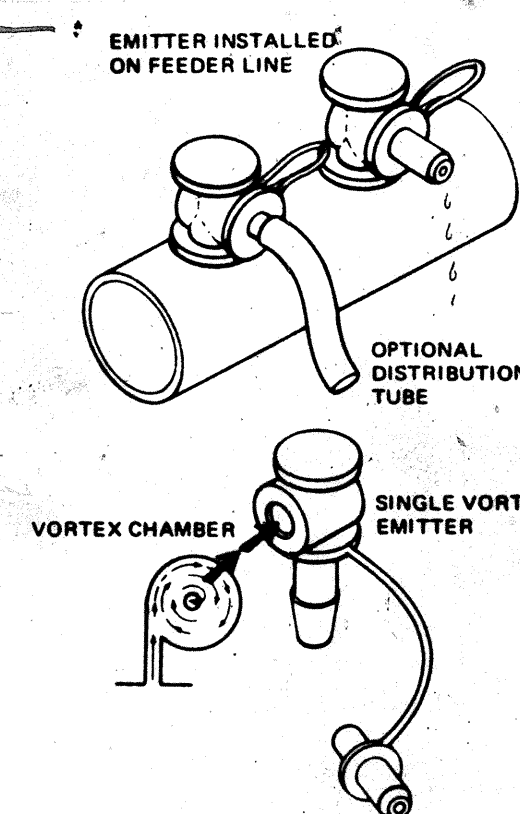


(E) TYP. VORTEX EMITTER
 12 N.T.S.

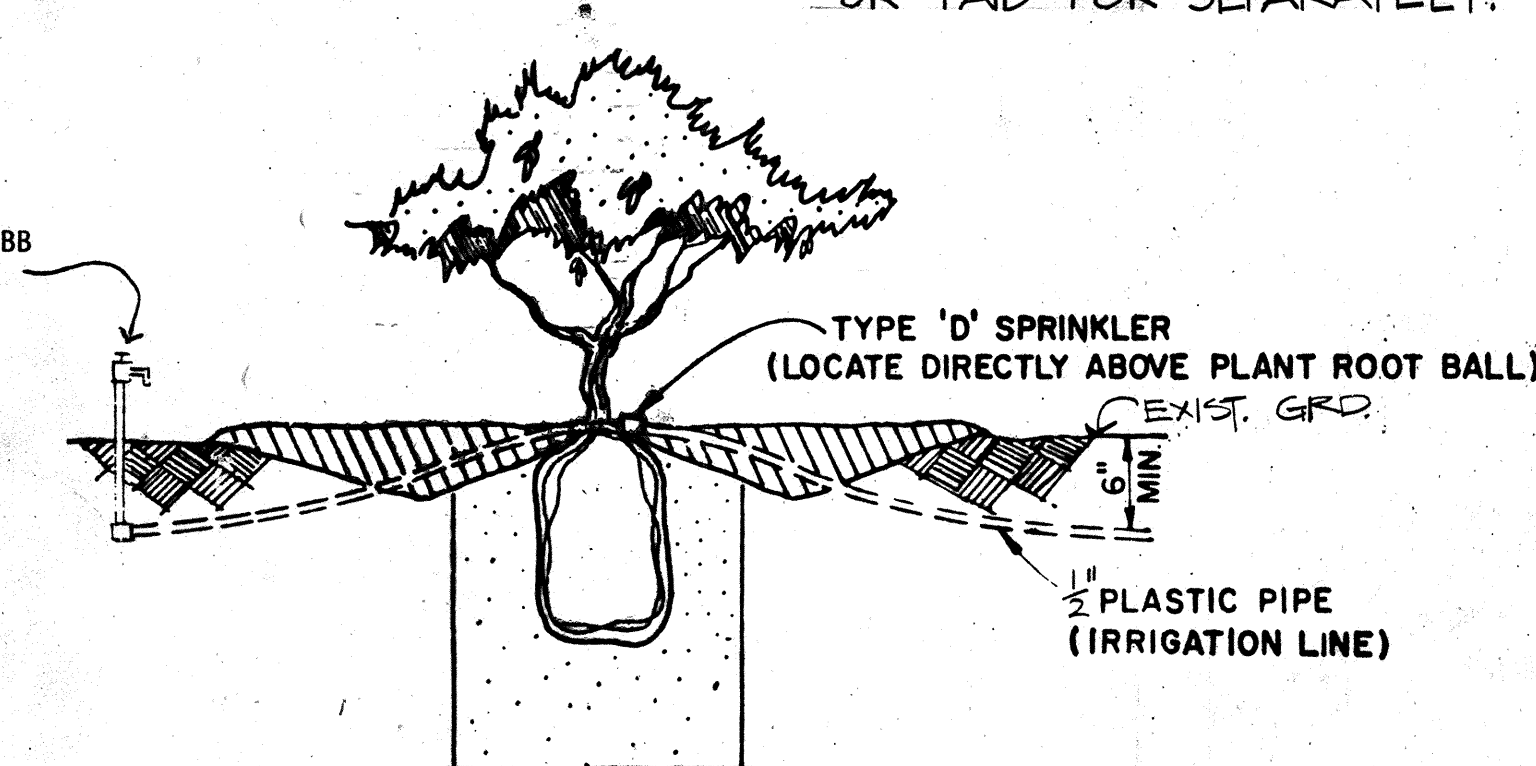


① PLASTIC PIPE
12 (IRRIGATION LINE)

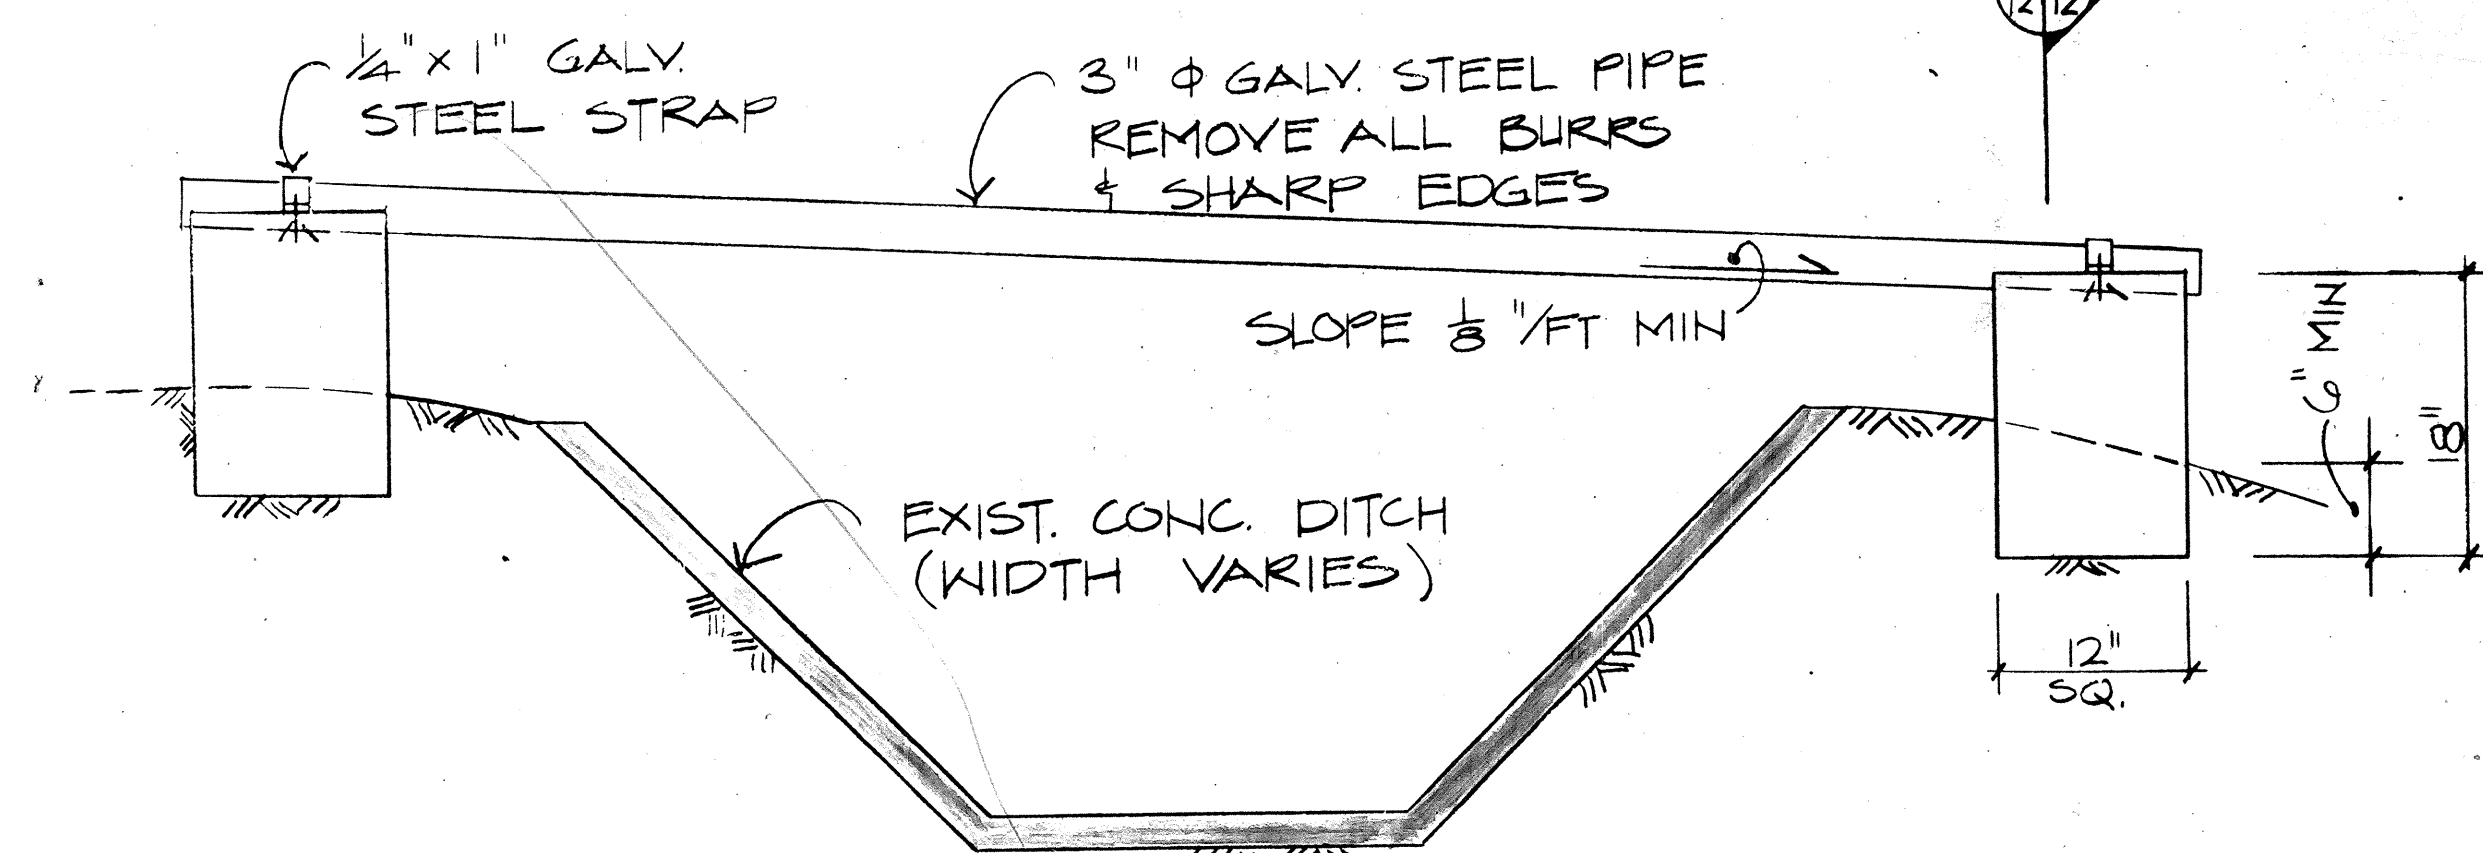

(J 12) DRAINAGE DITCH CROSSING DTL. (TYP.)
 HJS

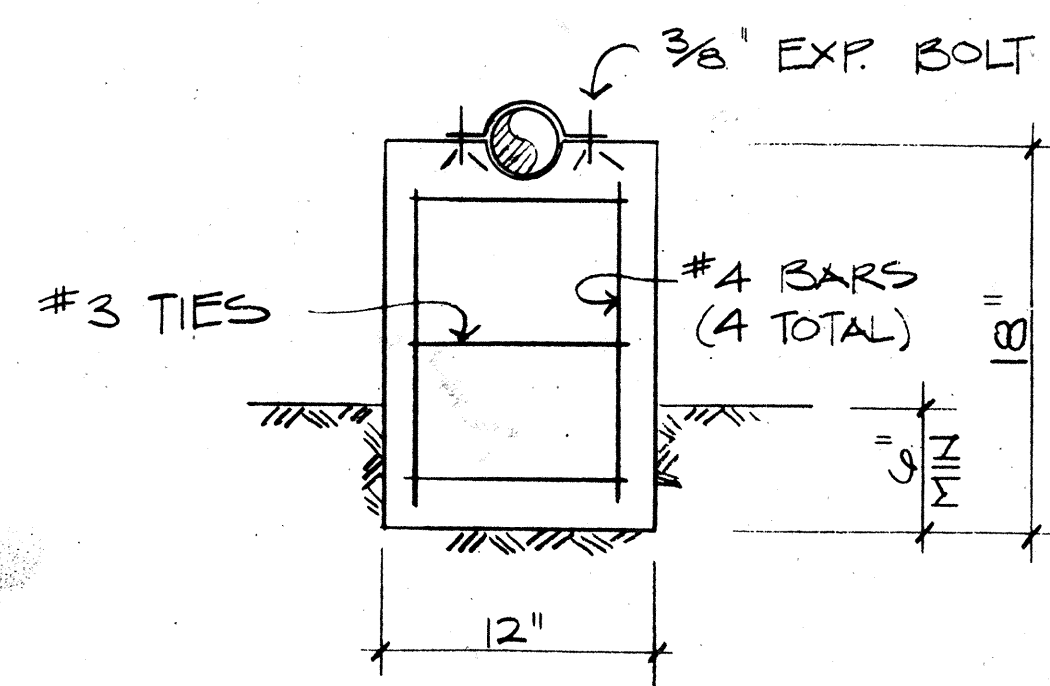

G SECTION
12/12 H.T.S.

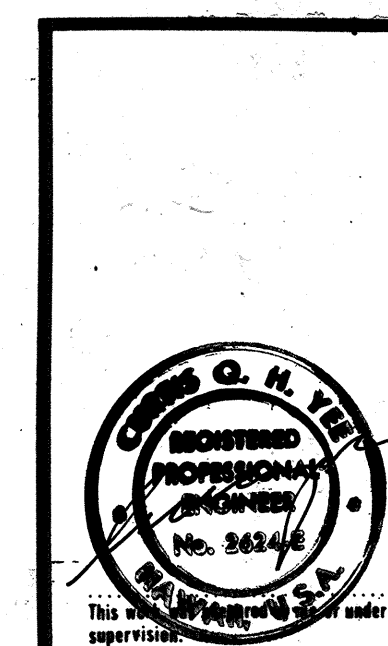

**STATE OF HAWAII
DEPARTMENT OF TRANSPORTATION
HIGHWAYS DIVISION**


PROJECT NO. I-H2-1(13):4

MILILANI INTERCHANGE


DETAILS

SHEET No. 12 OF 25 SHEETS


FED. ROAD DIST. NO.	STATE	FED. AID PROJ. NO.	FISCAL YEAR	SHEET NO.	TOTAL SHEETS
HAWAII	HAW.	I-H2-1(13):4	1977	22	34

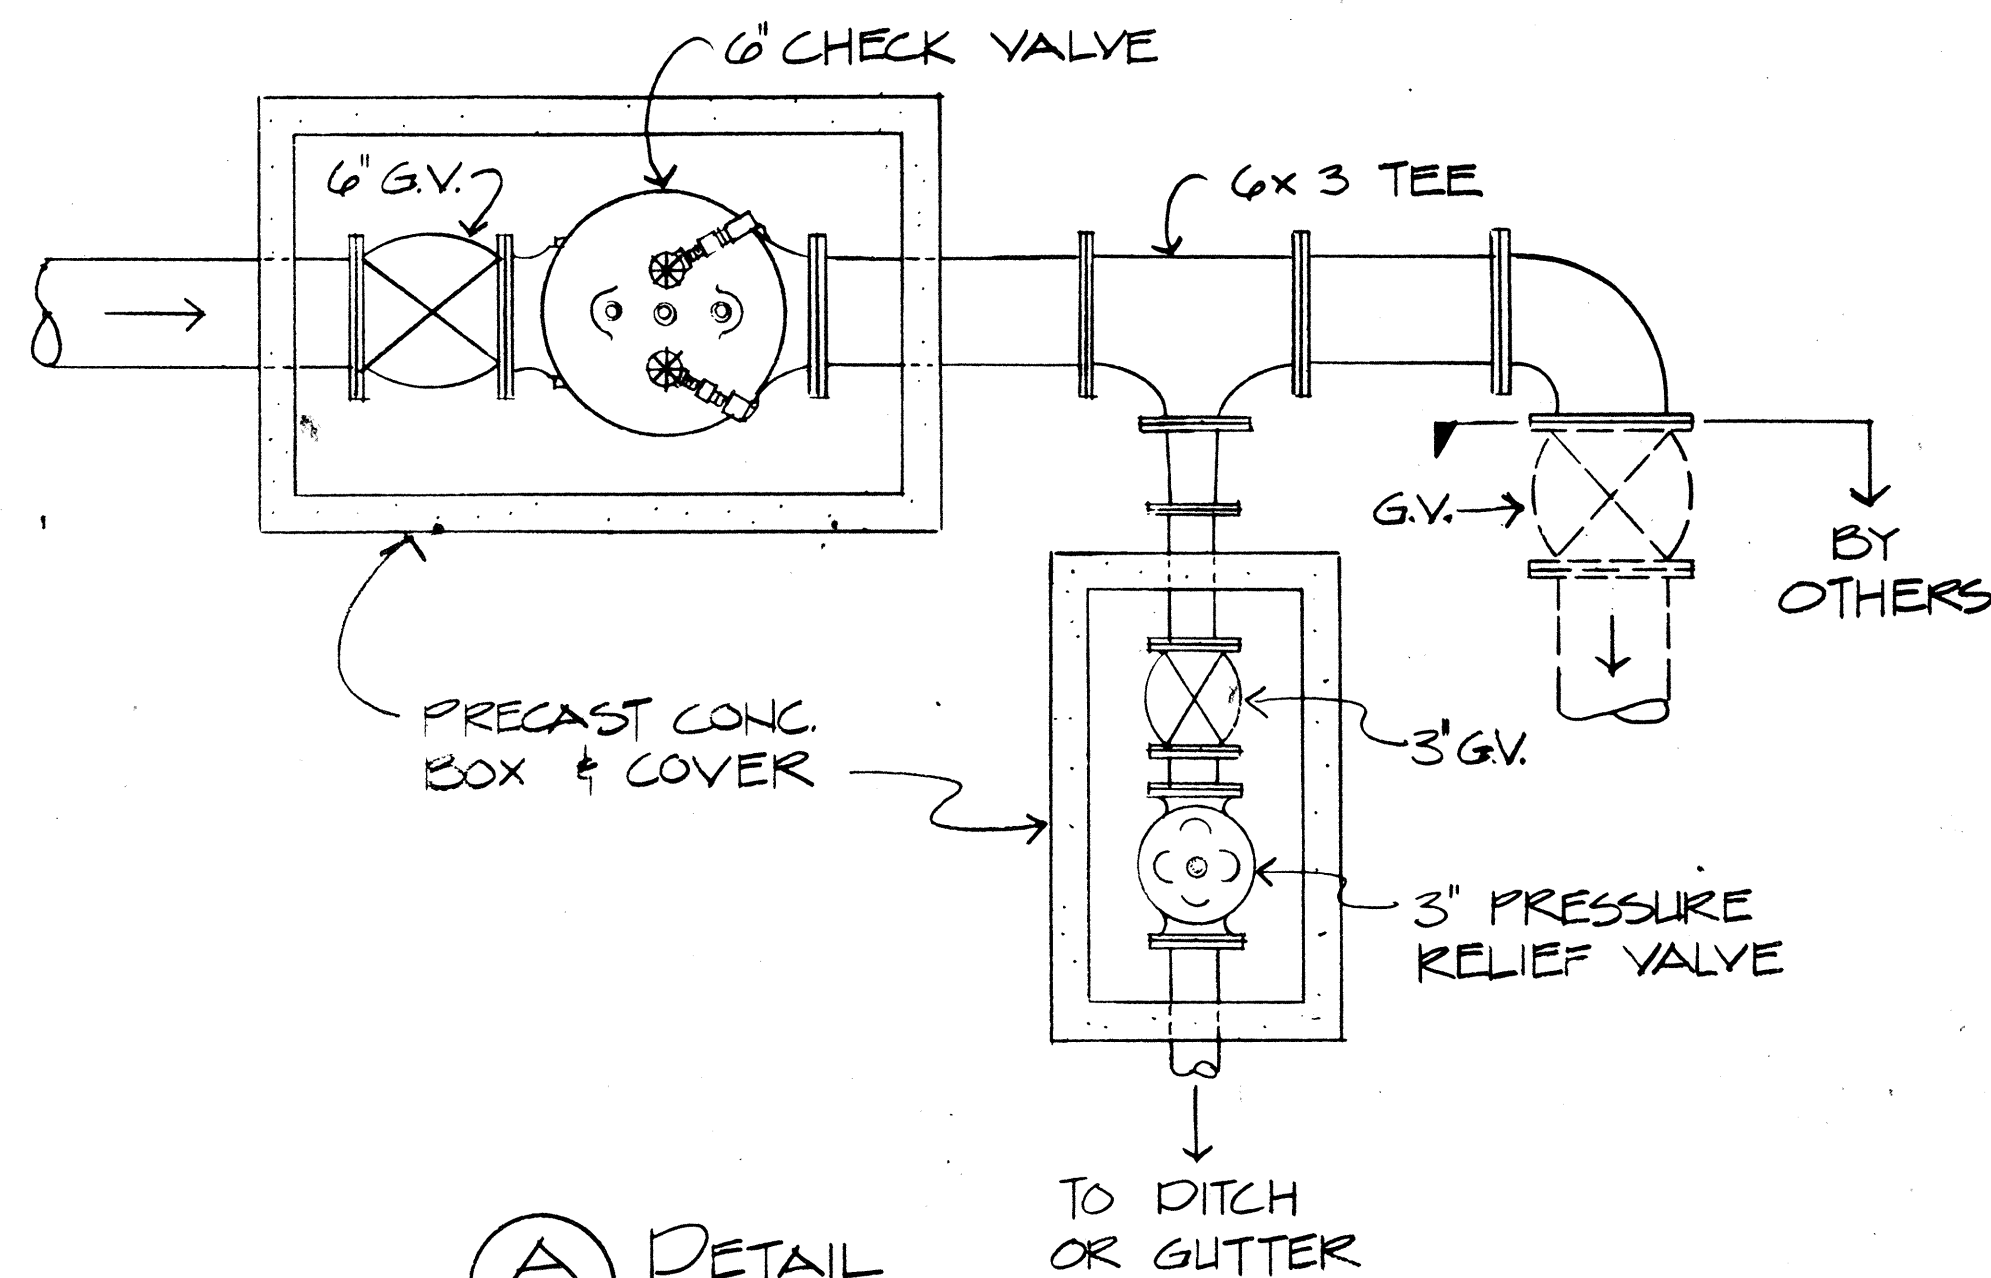


A DETAIL
13 N.T.S.

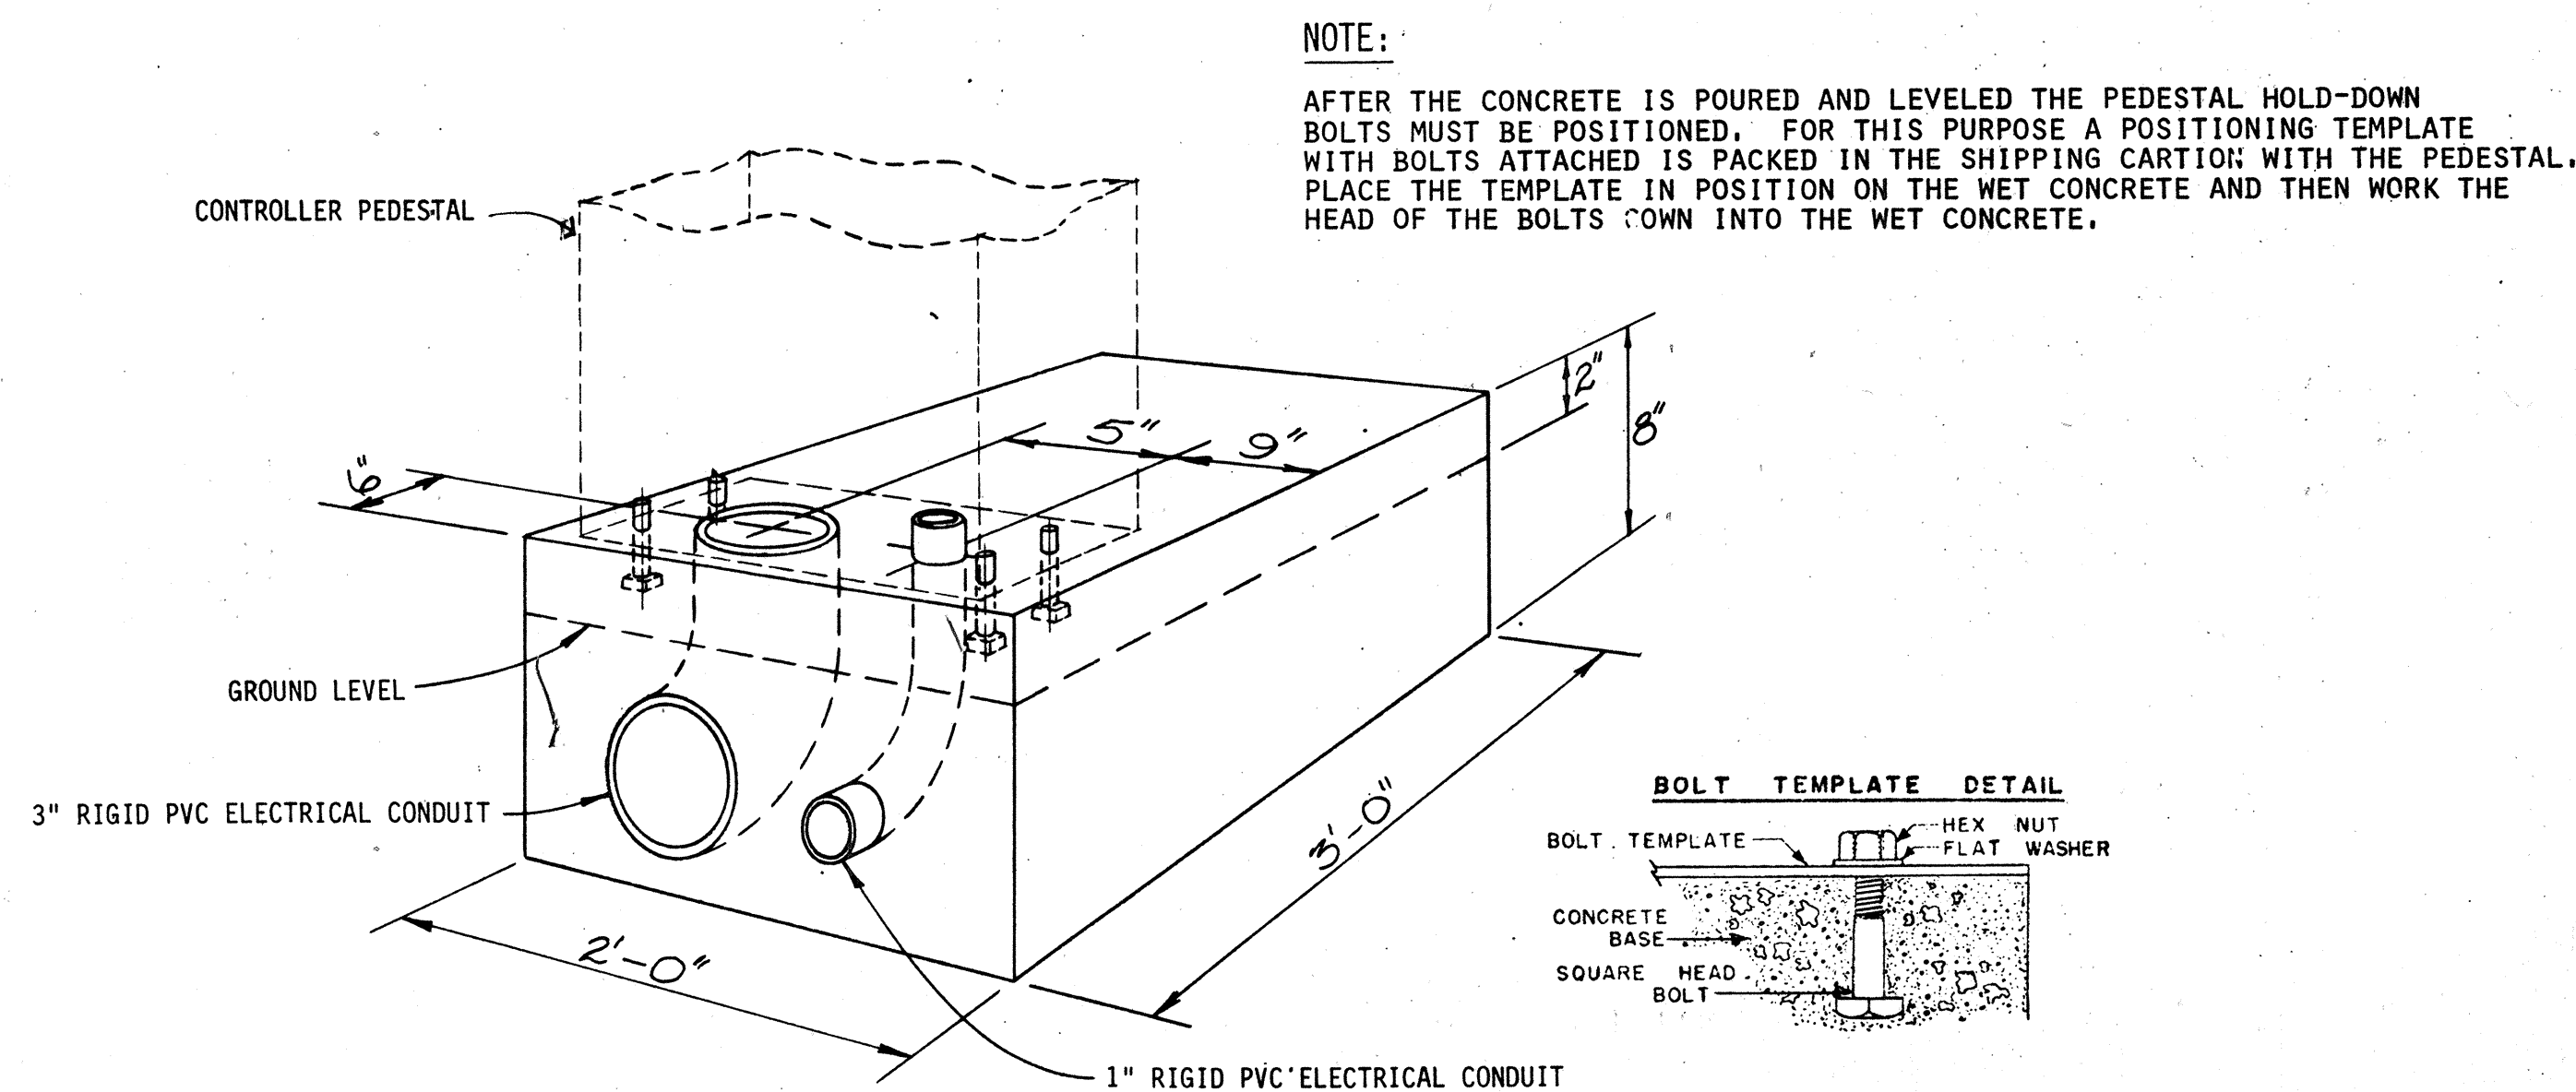


B DETAIL
13 N.T.S.

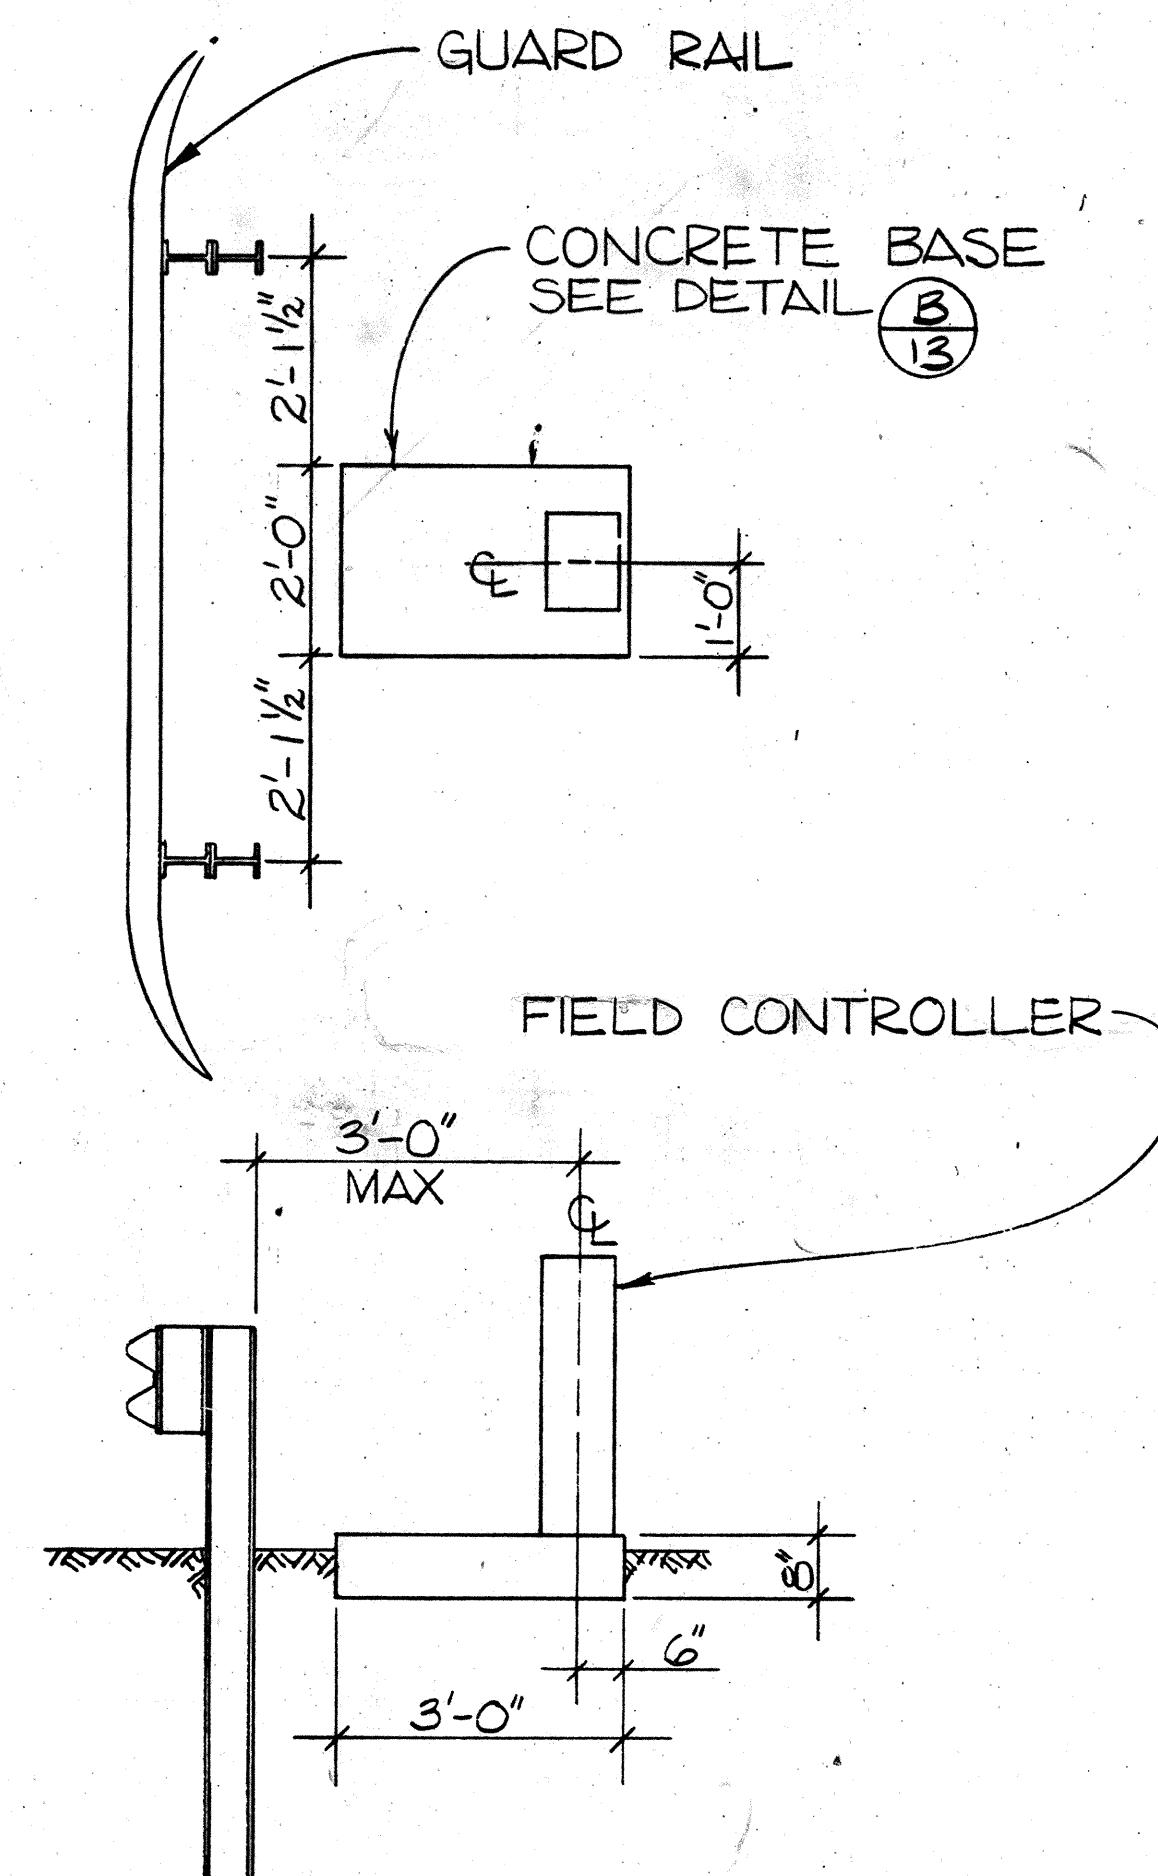


C DETAIL - TYP
13 SCALE: 1/2" = 1'-0"

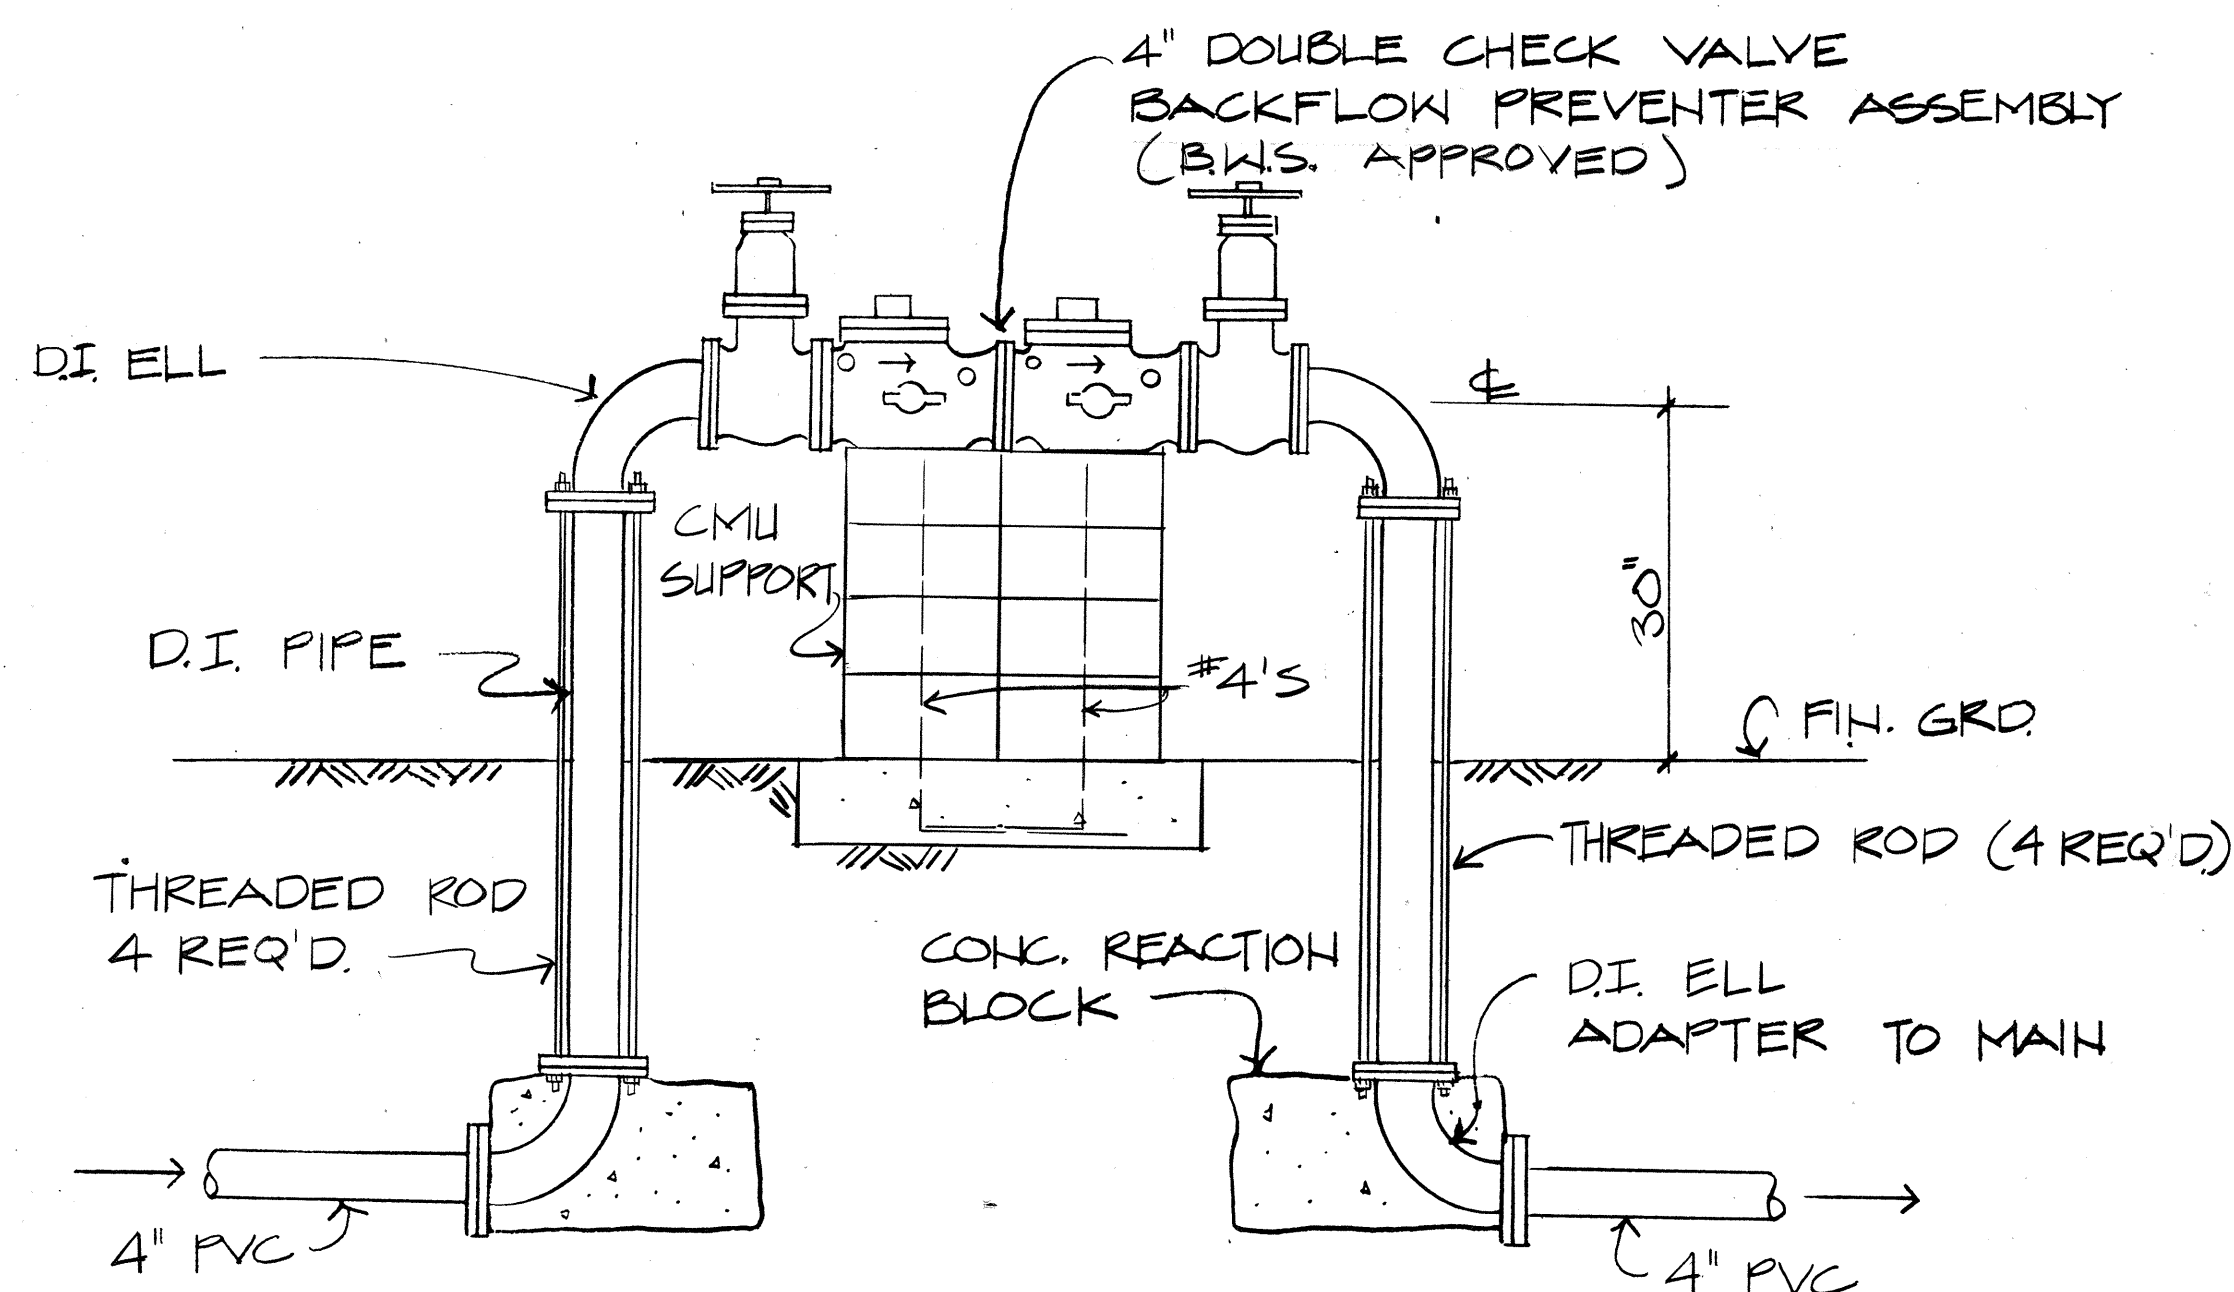


F BACKFLOW PREVENTER ASSEMBLY
13 N.T.S.

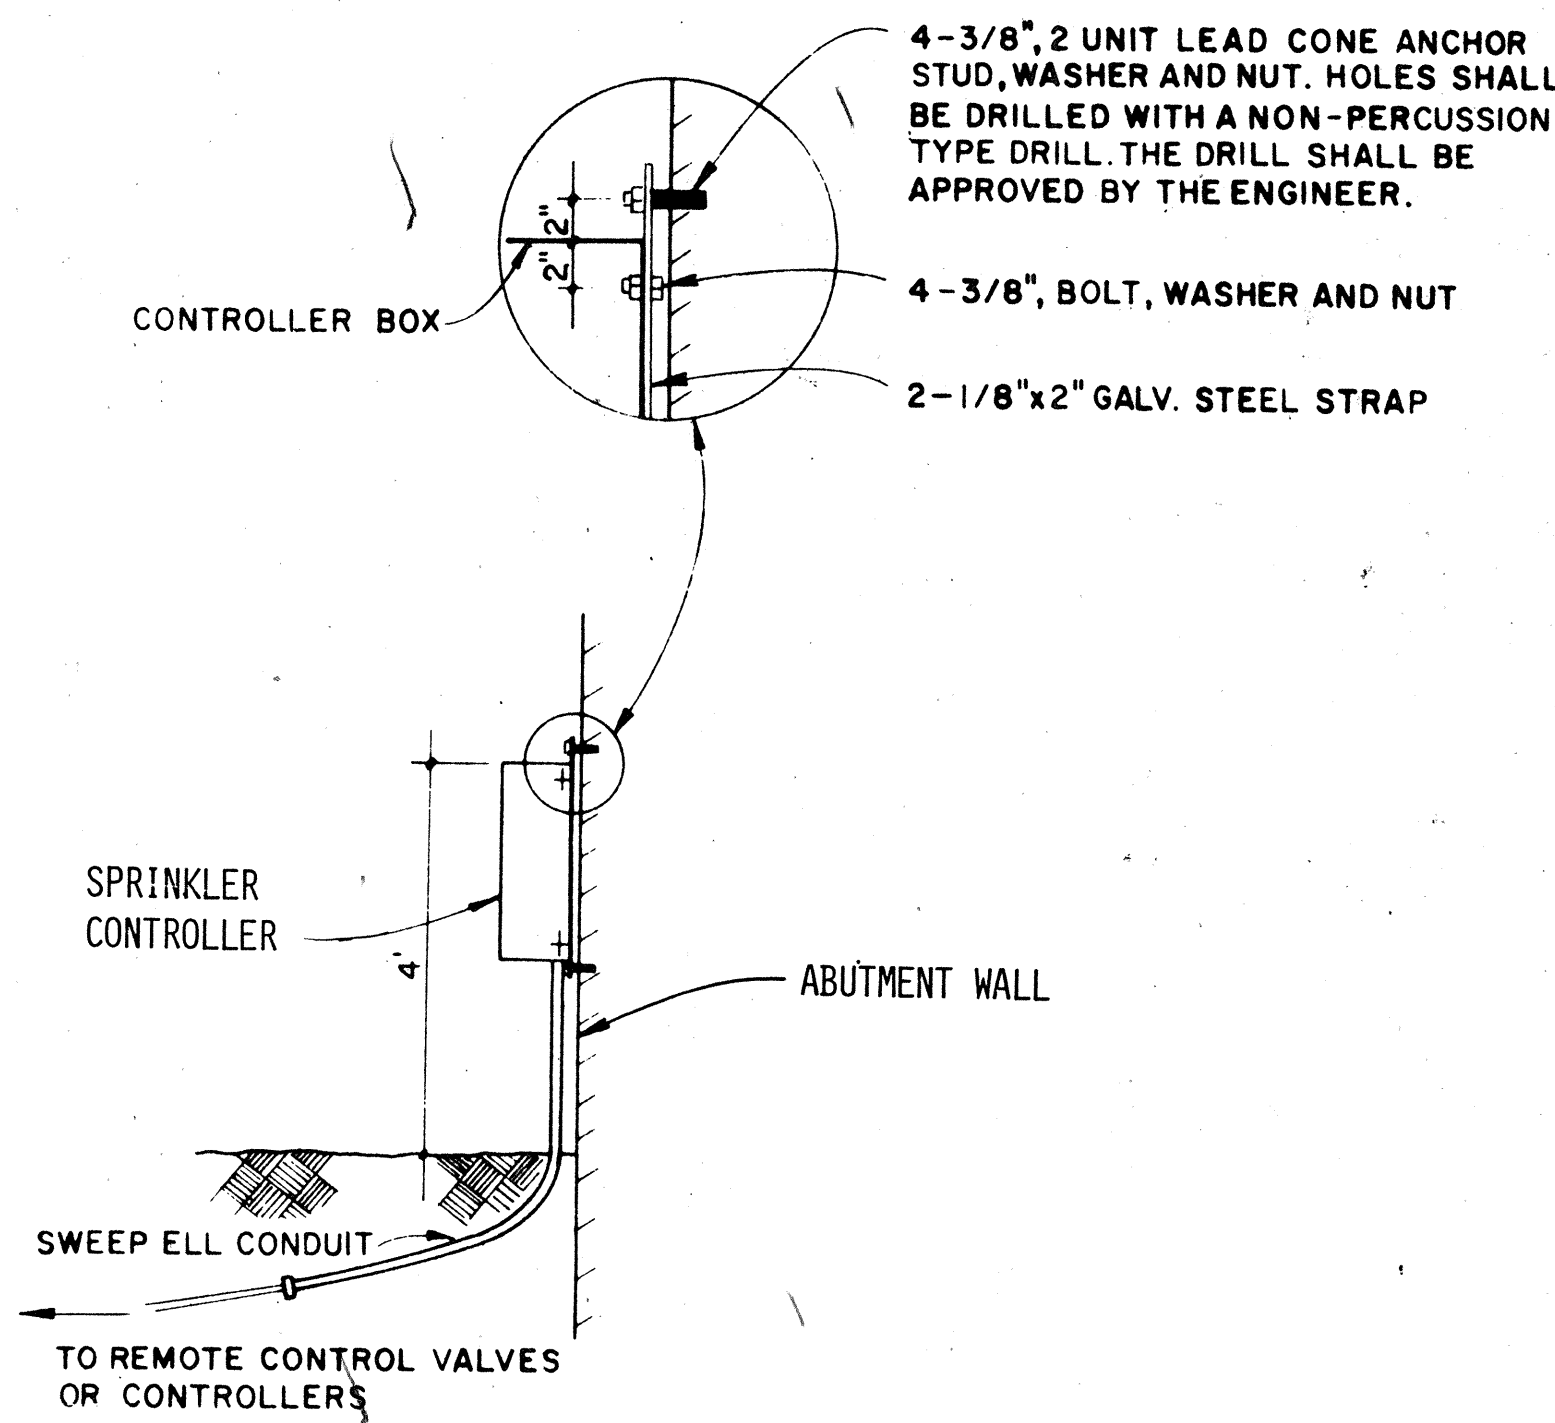

E FIELD CONTROLLERS ANCHORED TO WALL
13 N.T.S.

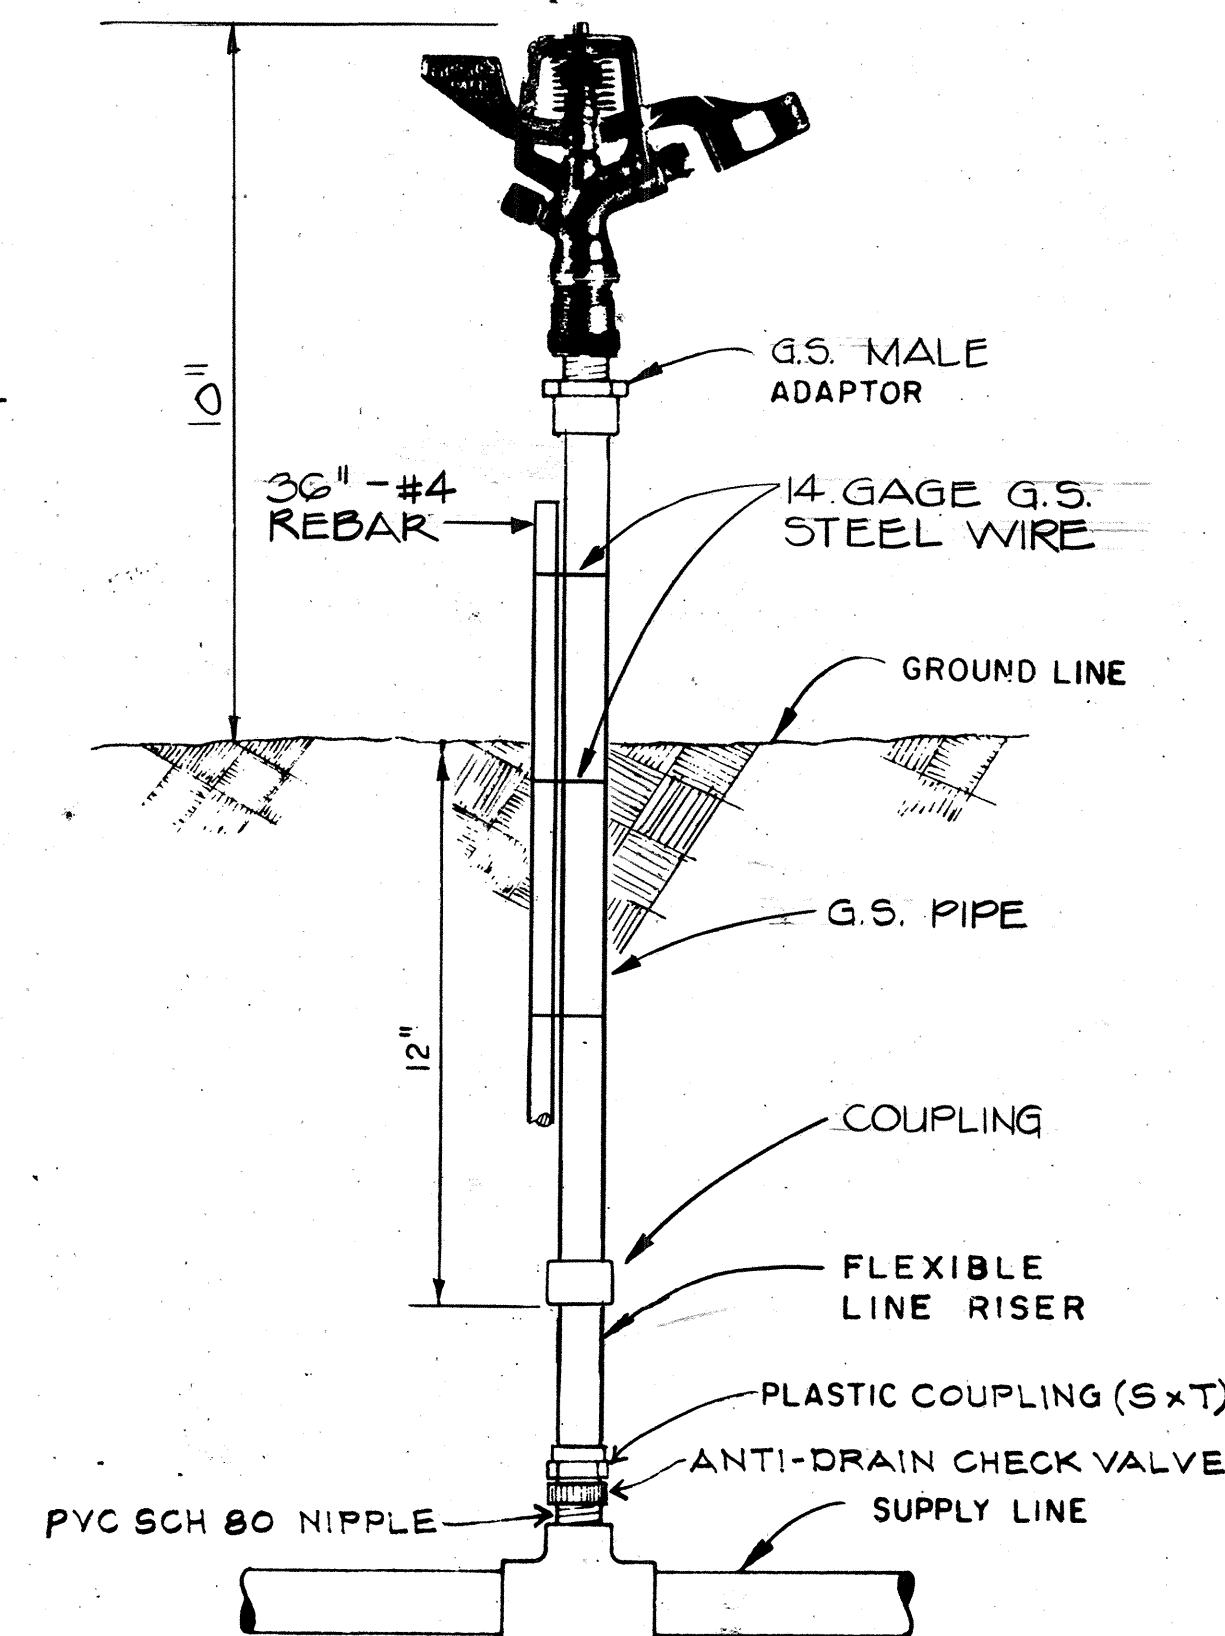

D DET - RISER
13 N.T.S.

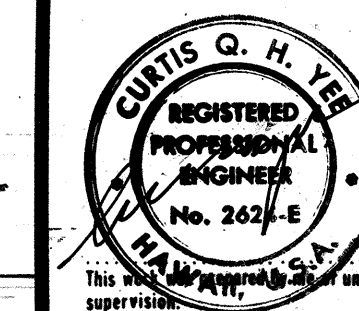


STATE OF HAWAII
DEPARTMENT OF TRANSPORTATION
HIGHWAYS DIVISION
PROJECT NO. I-H2-1(13):4
MILILANI INTERCHANGE
DETAILS

SHEET No. 13 OF 25 SHEETS


11/17/76	Detail 13 not applicable for Central Programmer per Addendum No. 1.
DATE	REVISION

DATE	11/17/76
DESIGNED BY	CHS
CHECKED BY	CHS
NOTED BY	CHS
QUANTITIES BY	CHS
ORIGINAL PLAN	NO.


FED. ROAD DIST. NO.	STATE	FED. AID PROJ. NO.	FISCAL YEAR	SHEET NO.	TOTAL SHEETS
HAWAII	HAW.	I-H2-1(13):4	1979	002251	34

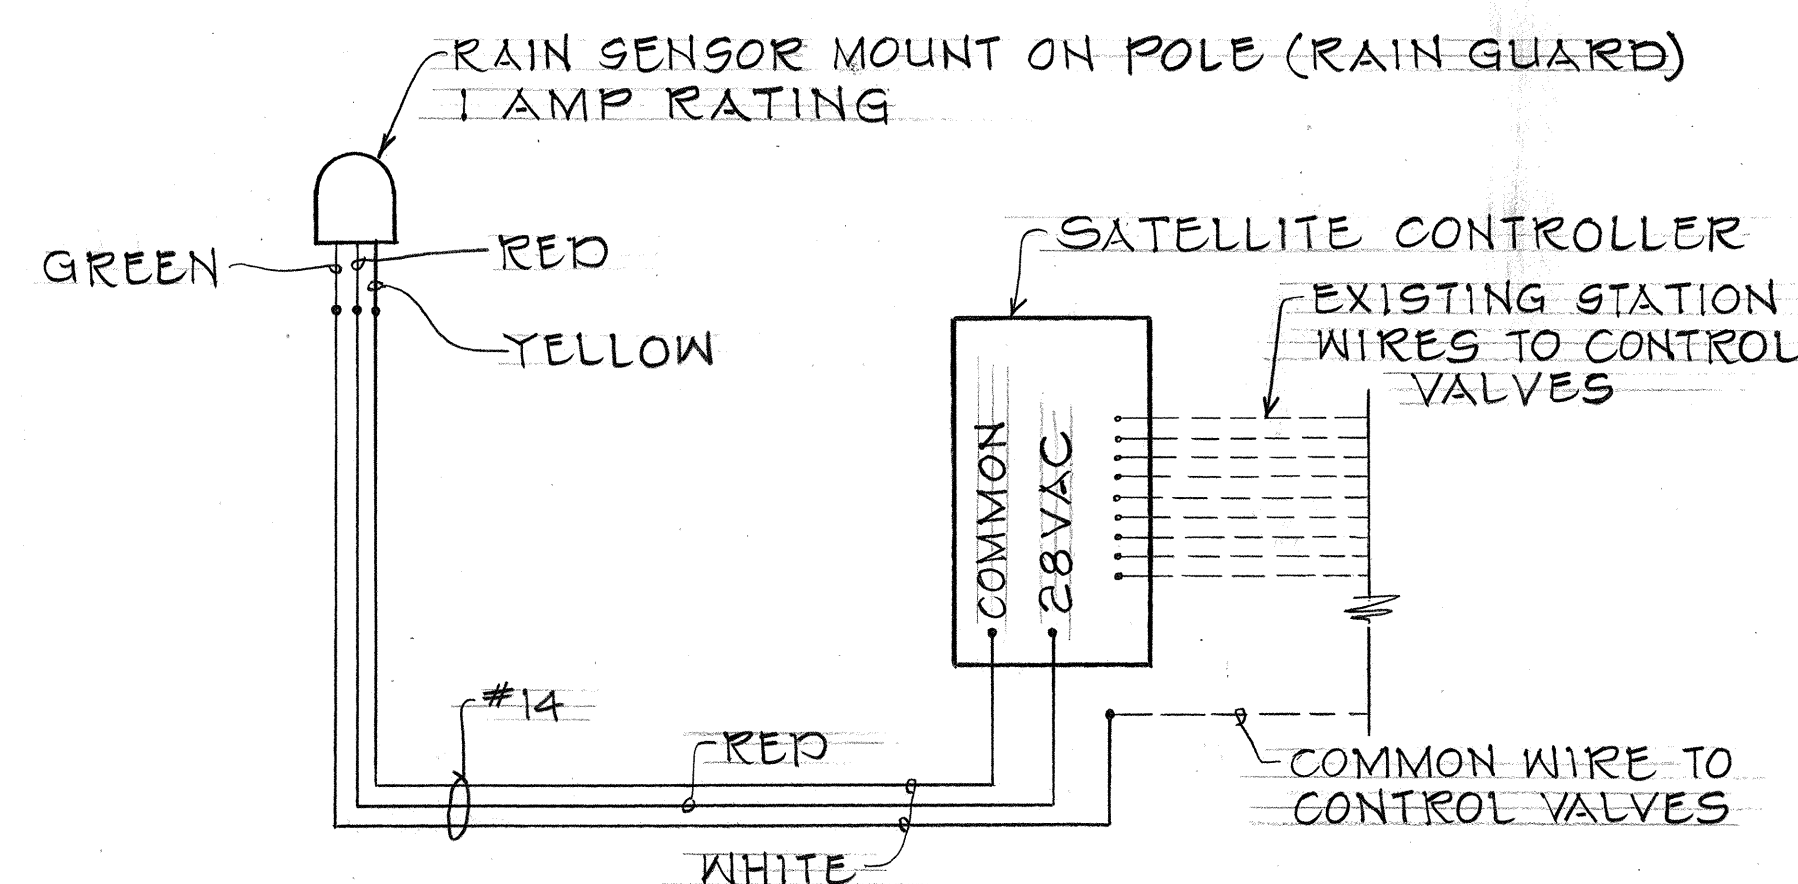

RAIN SENSOR WIRE DIAGRAM AT SATELLITE CONTROLLER

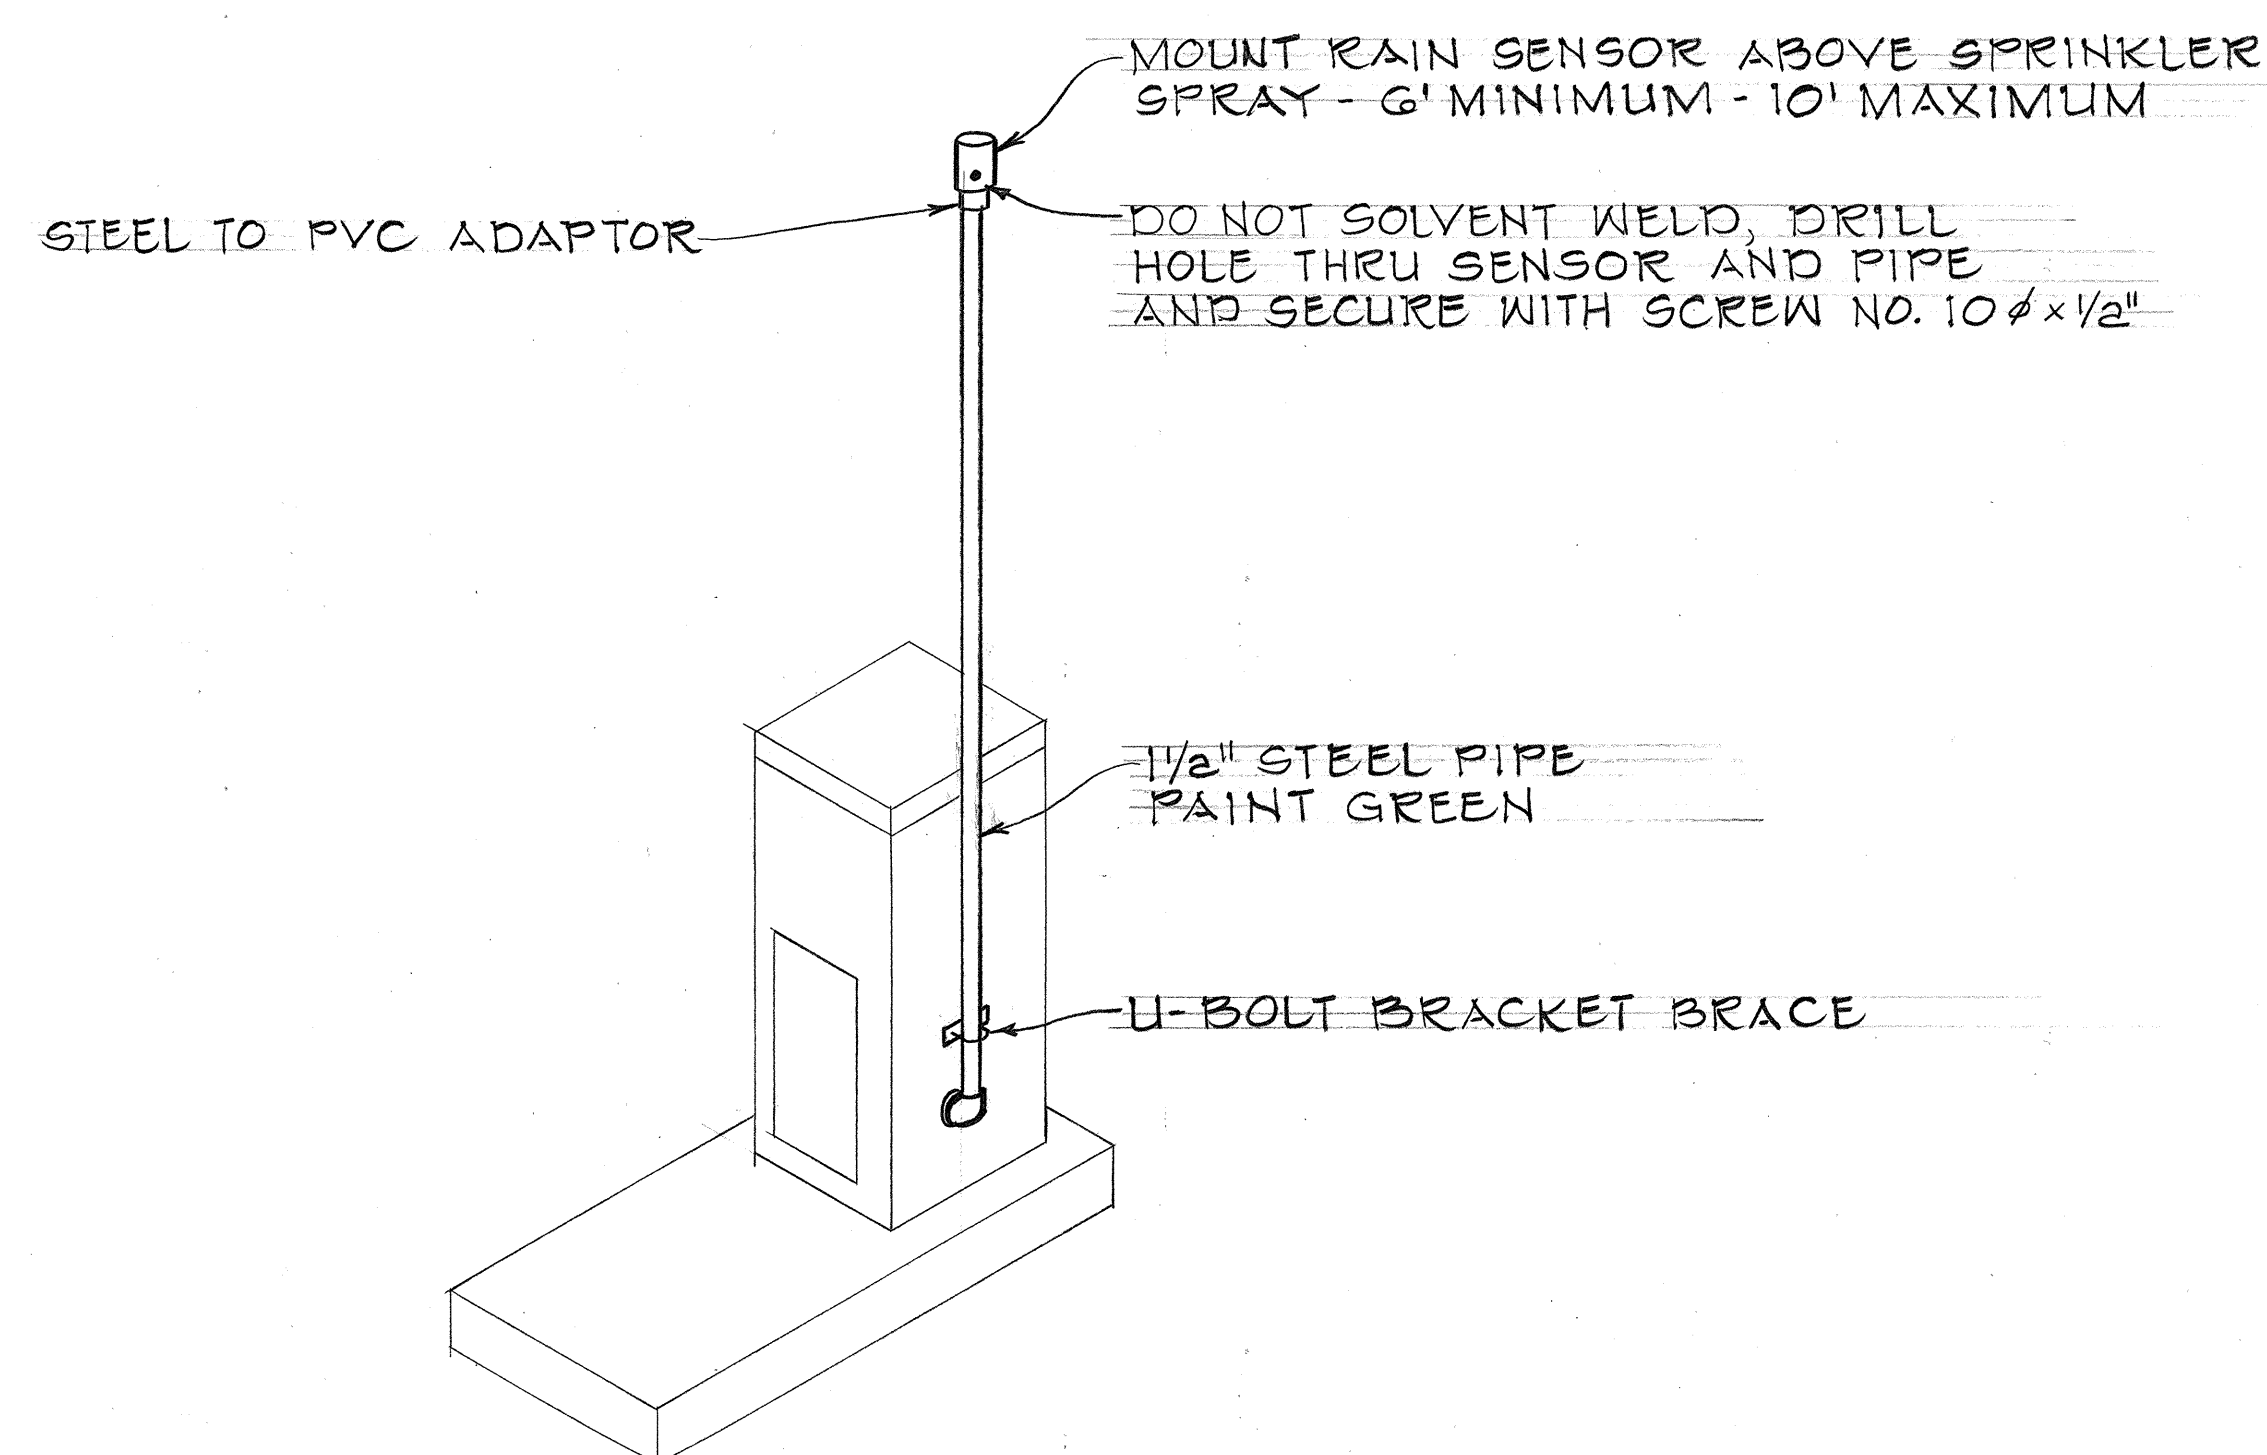

TYPICAL RAIN SENSOR INSTALLATION AT SATELLITE CONTROLLER

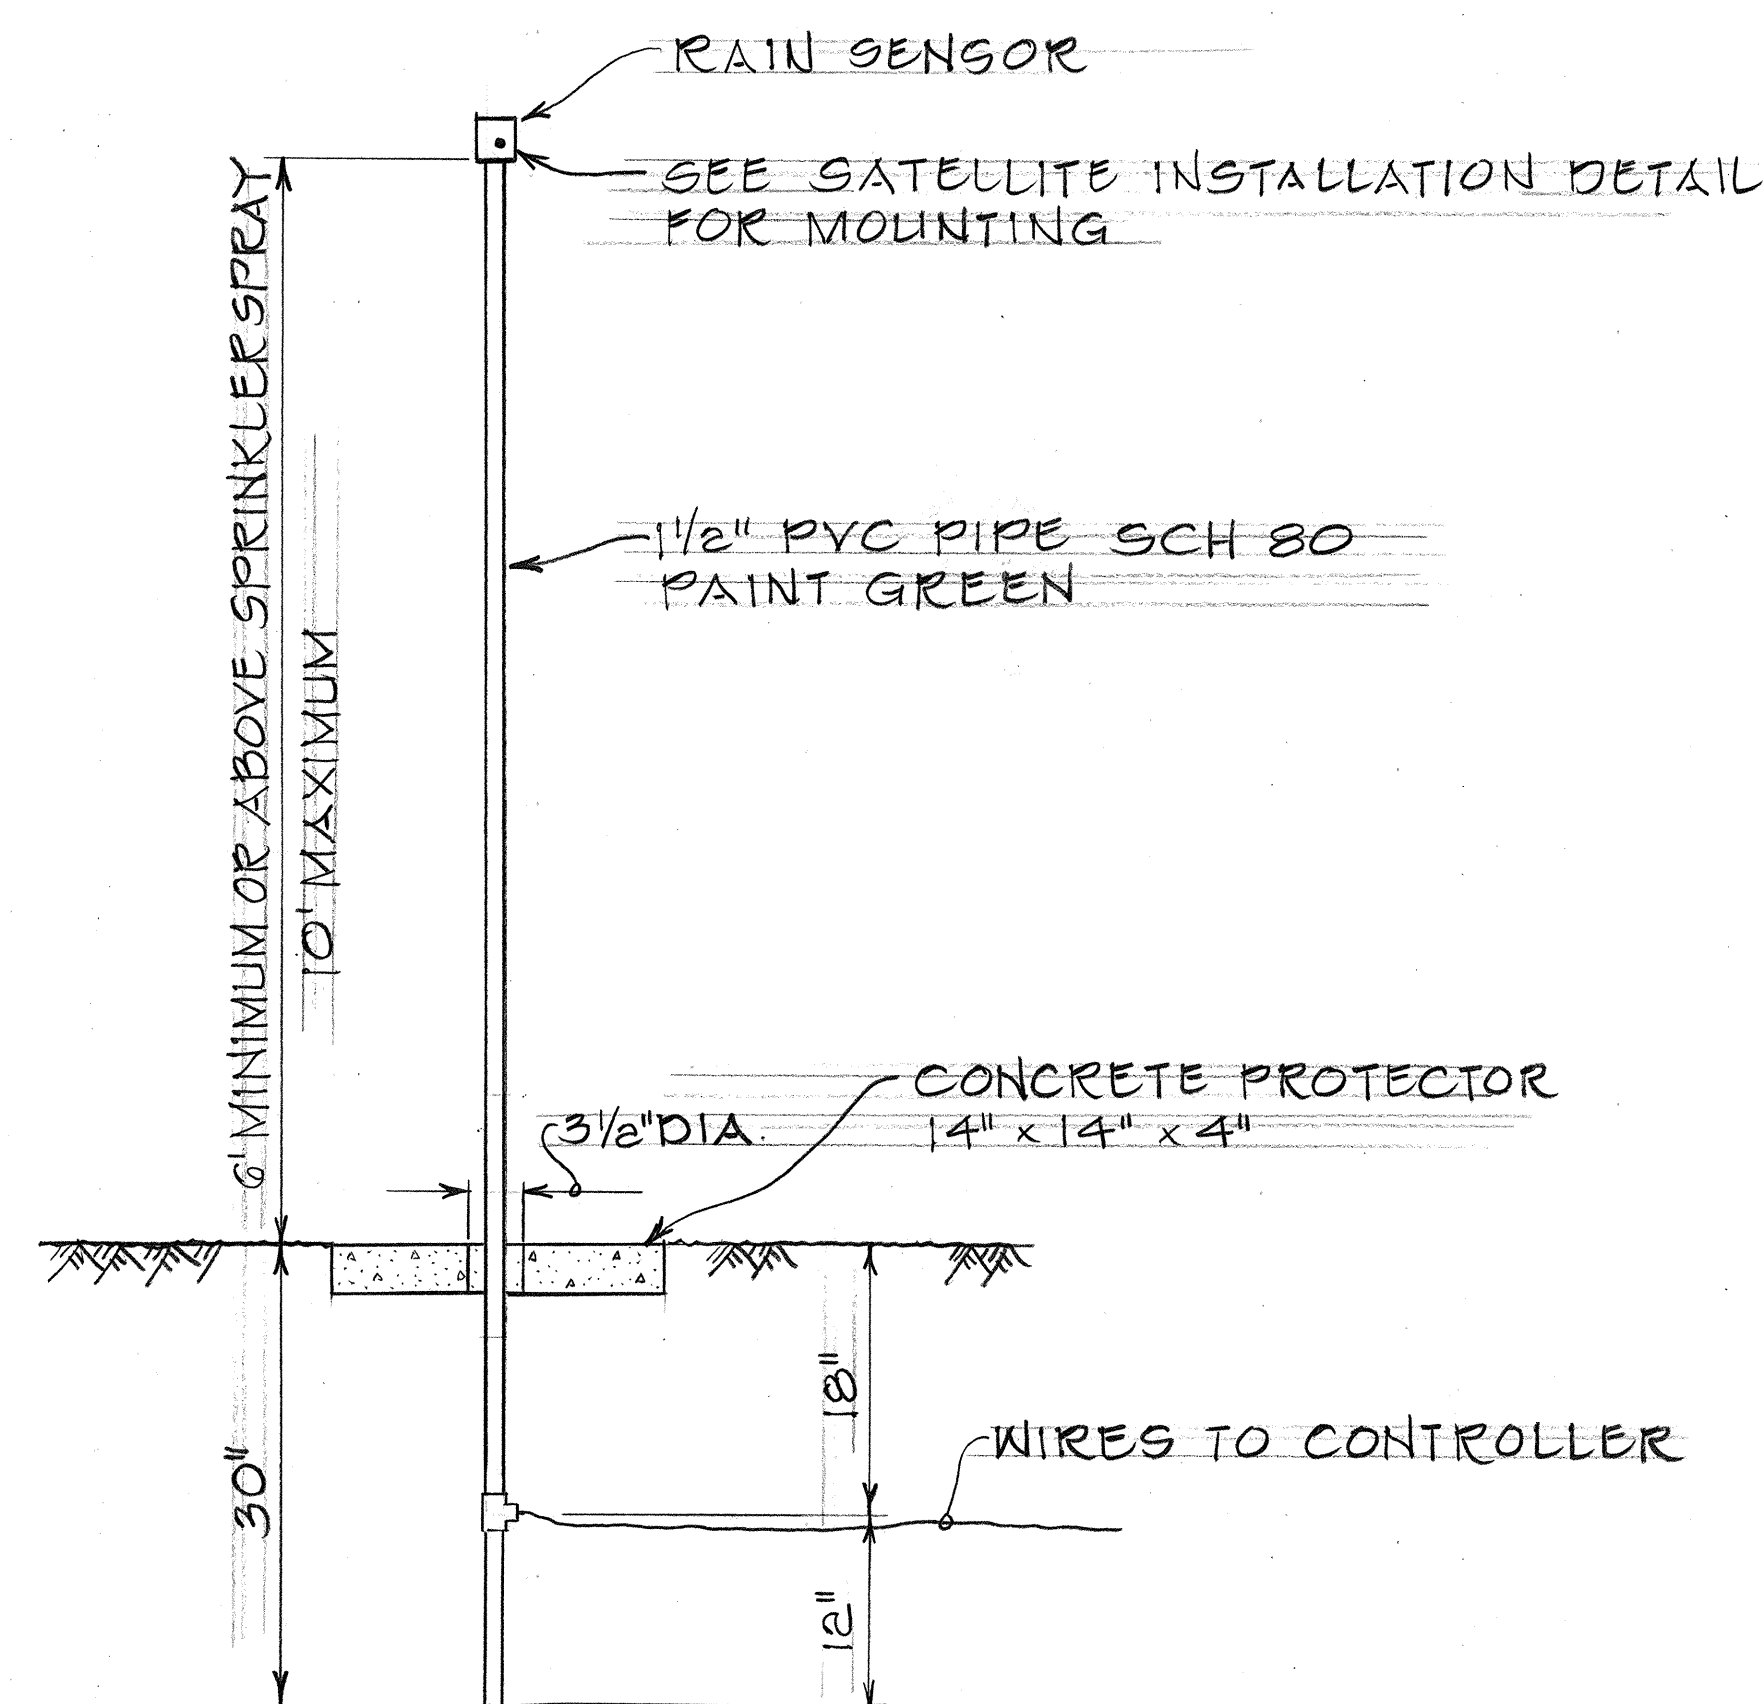

TYPICAL DETAIL RAIN SENSOR ON POLE

SURVEY PLOTTED BY	DATE
DRAWN BY	
TRACED BY	
CHECKED BY	
QUANTITIES BY	
CHECKED BY	
ORIGINAL PLAN	
NOTE BOOK	
No.	

31 Jan 79 Sheet added to Contract Plan to show additional details.

DATE REVISION

STATE OF HAWAII
DEPARTMENT OF TRANSPORTATION
LAND TRANSPORTATION FACILITIES DIVISION
IRRIGATION SYSTEM

DETAILS





INTERSTATE ROUTE H-2
PROJ. NO. I-H2-1(13):4

Not to Scale Date: Jan 1979

SHEET NO. 13A OF 25 SHEETS

0022 S-1

FED. ROAD DIST. NO.	STATE	FED. AID PROJ. NO.	FISCAL YEAR	SHEET NO.	TOTAL SHEETS
HAWAII	HAW.	I-H2-1(13):4	1977	23	34

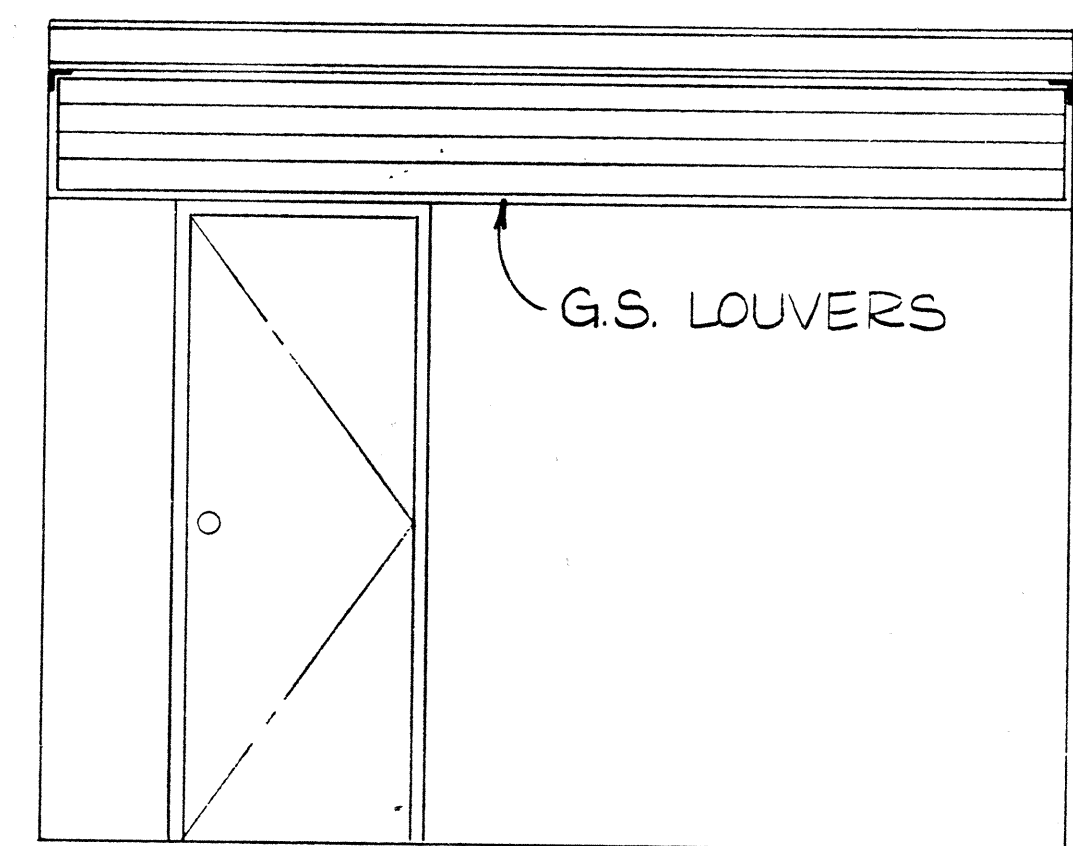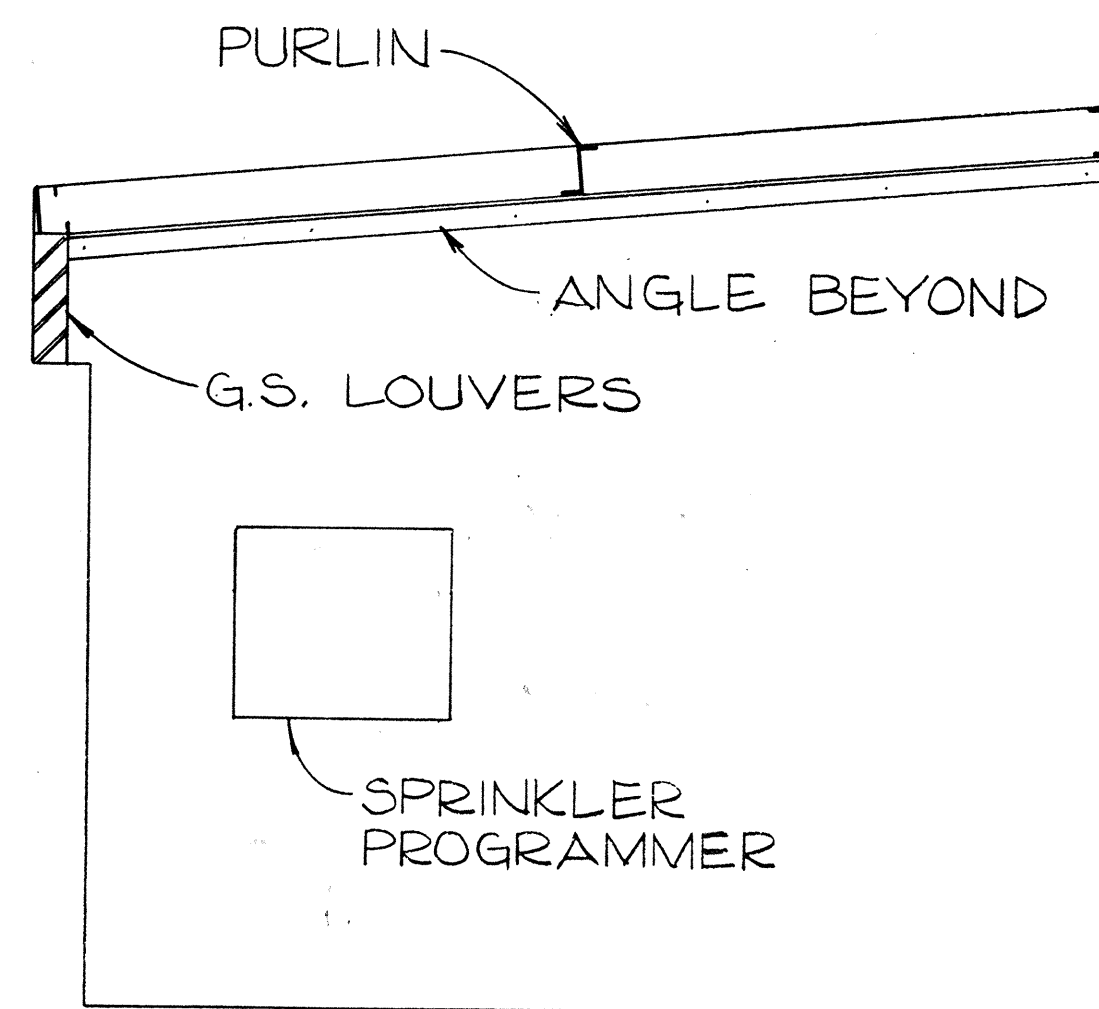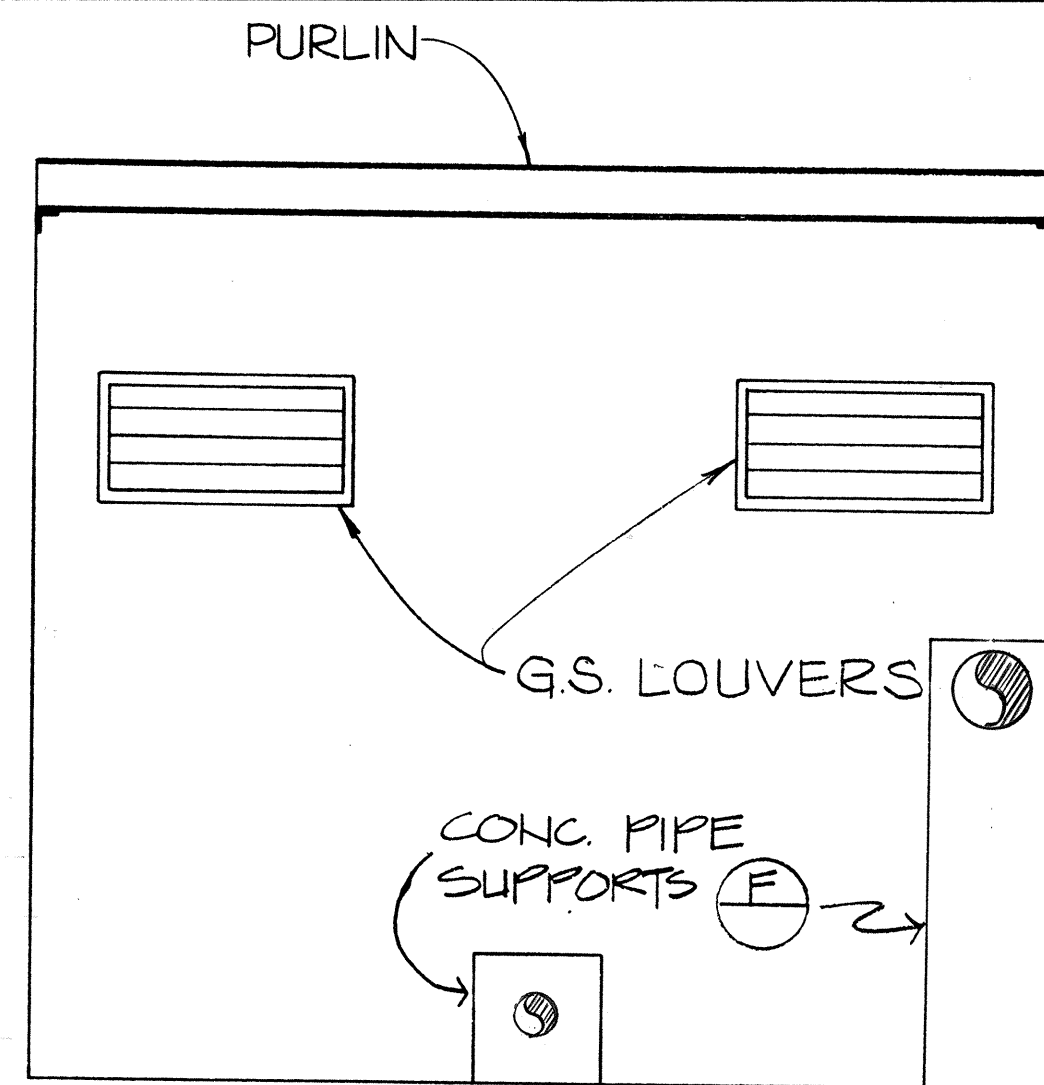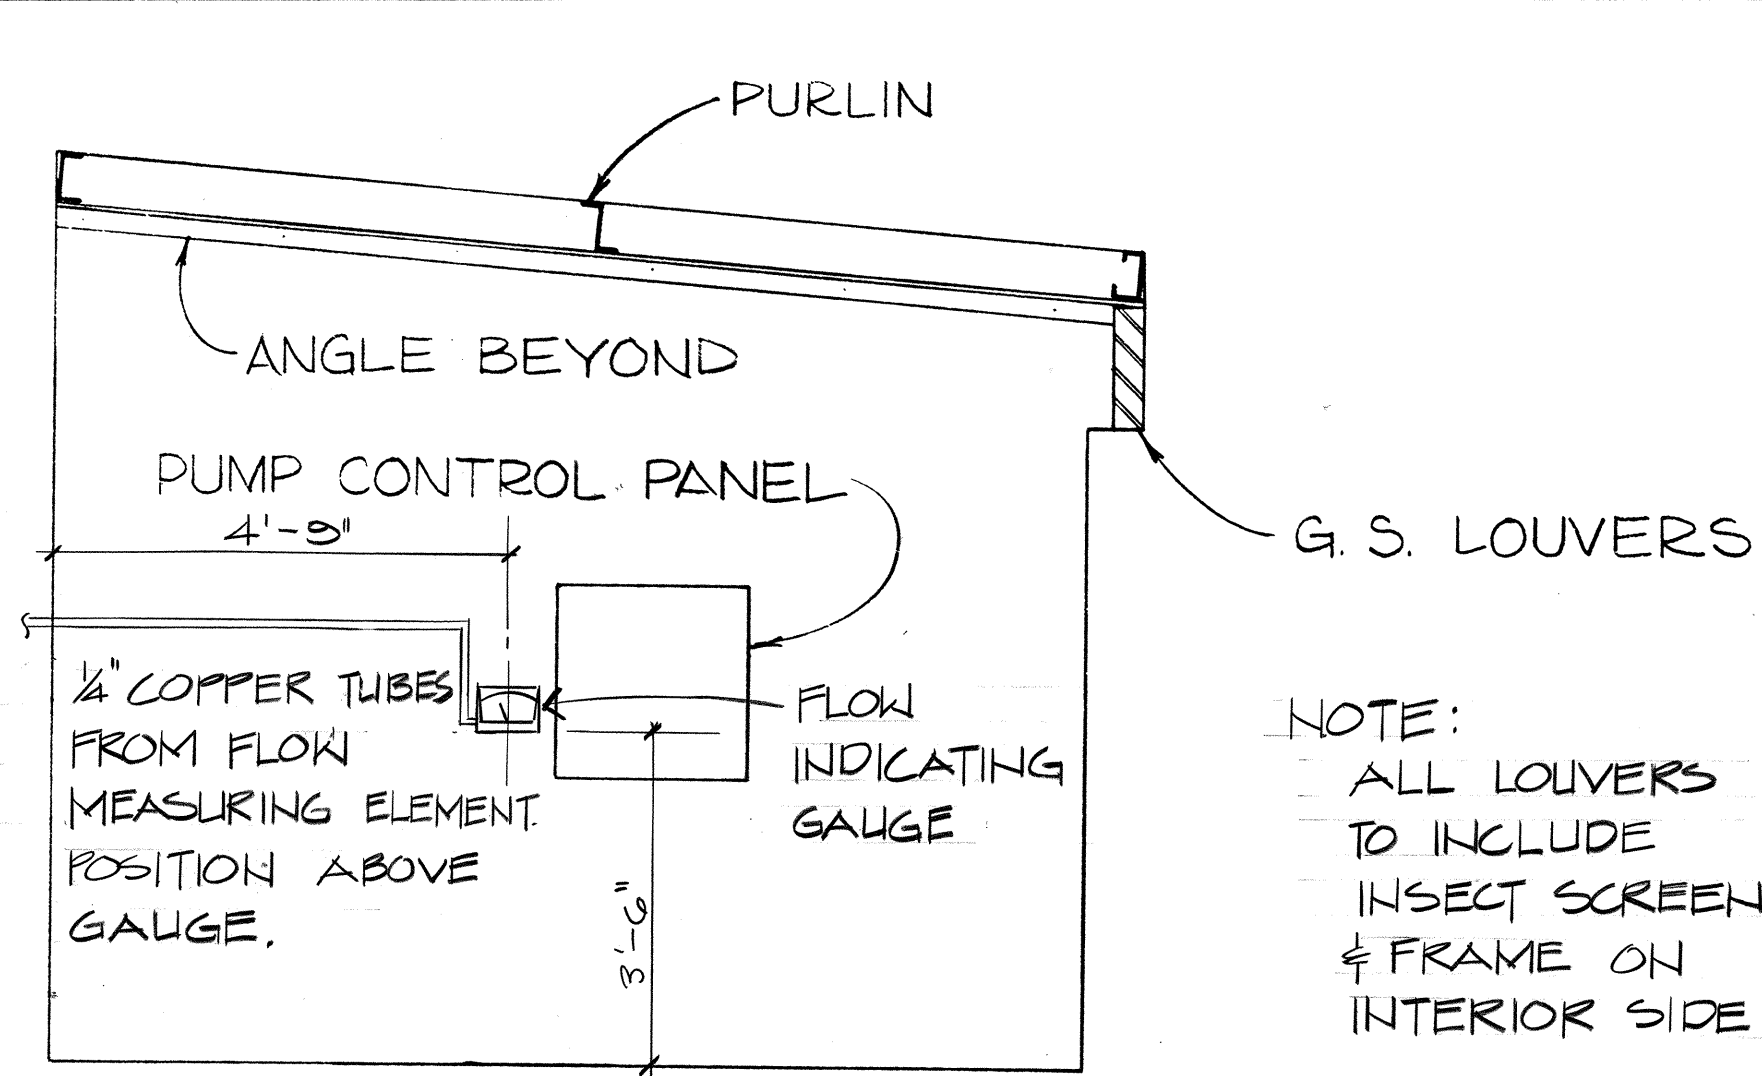


(W) 14 INTERIOR ELEVATION "W"
SCALE: 1/2" = 1'-0"

(Y) 14 INTERIOR ELEVATION "Y"
SCALE: 1/2" = 1'-0"

(X) 14 INTERIOR ELEVATION "X"
SCALE: 1/2" = 1'-0"


(Z) 14 INTERIOR ELEVATION "Z"
SCALE: 1/2" = 1'-0"

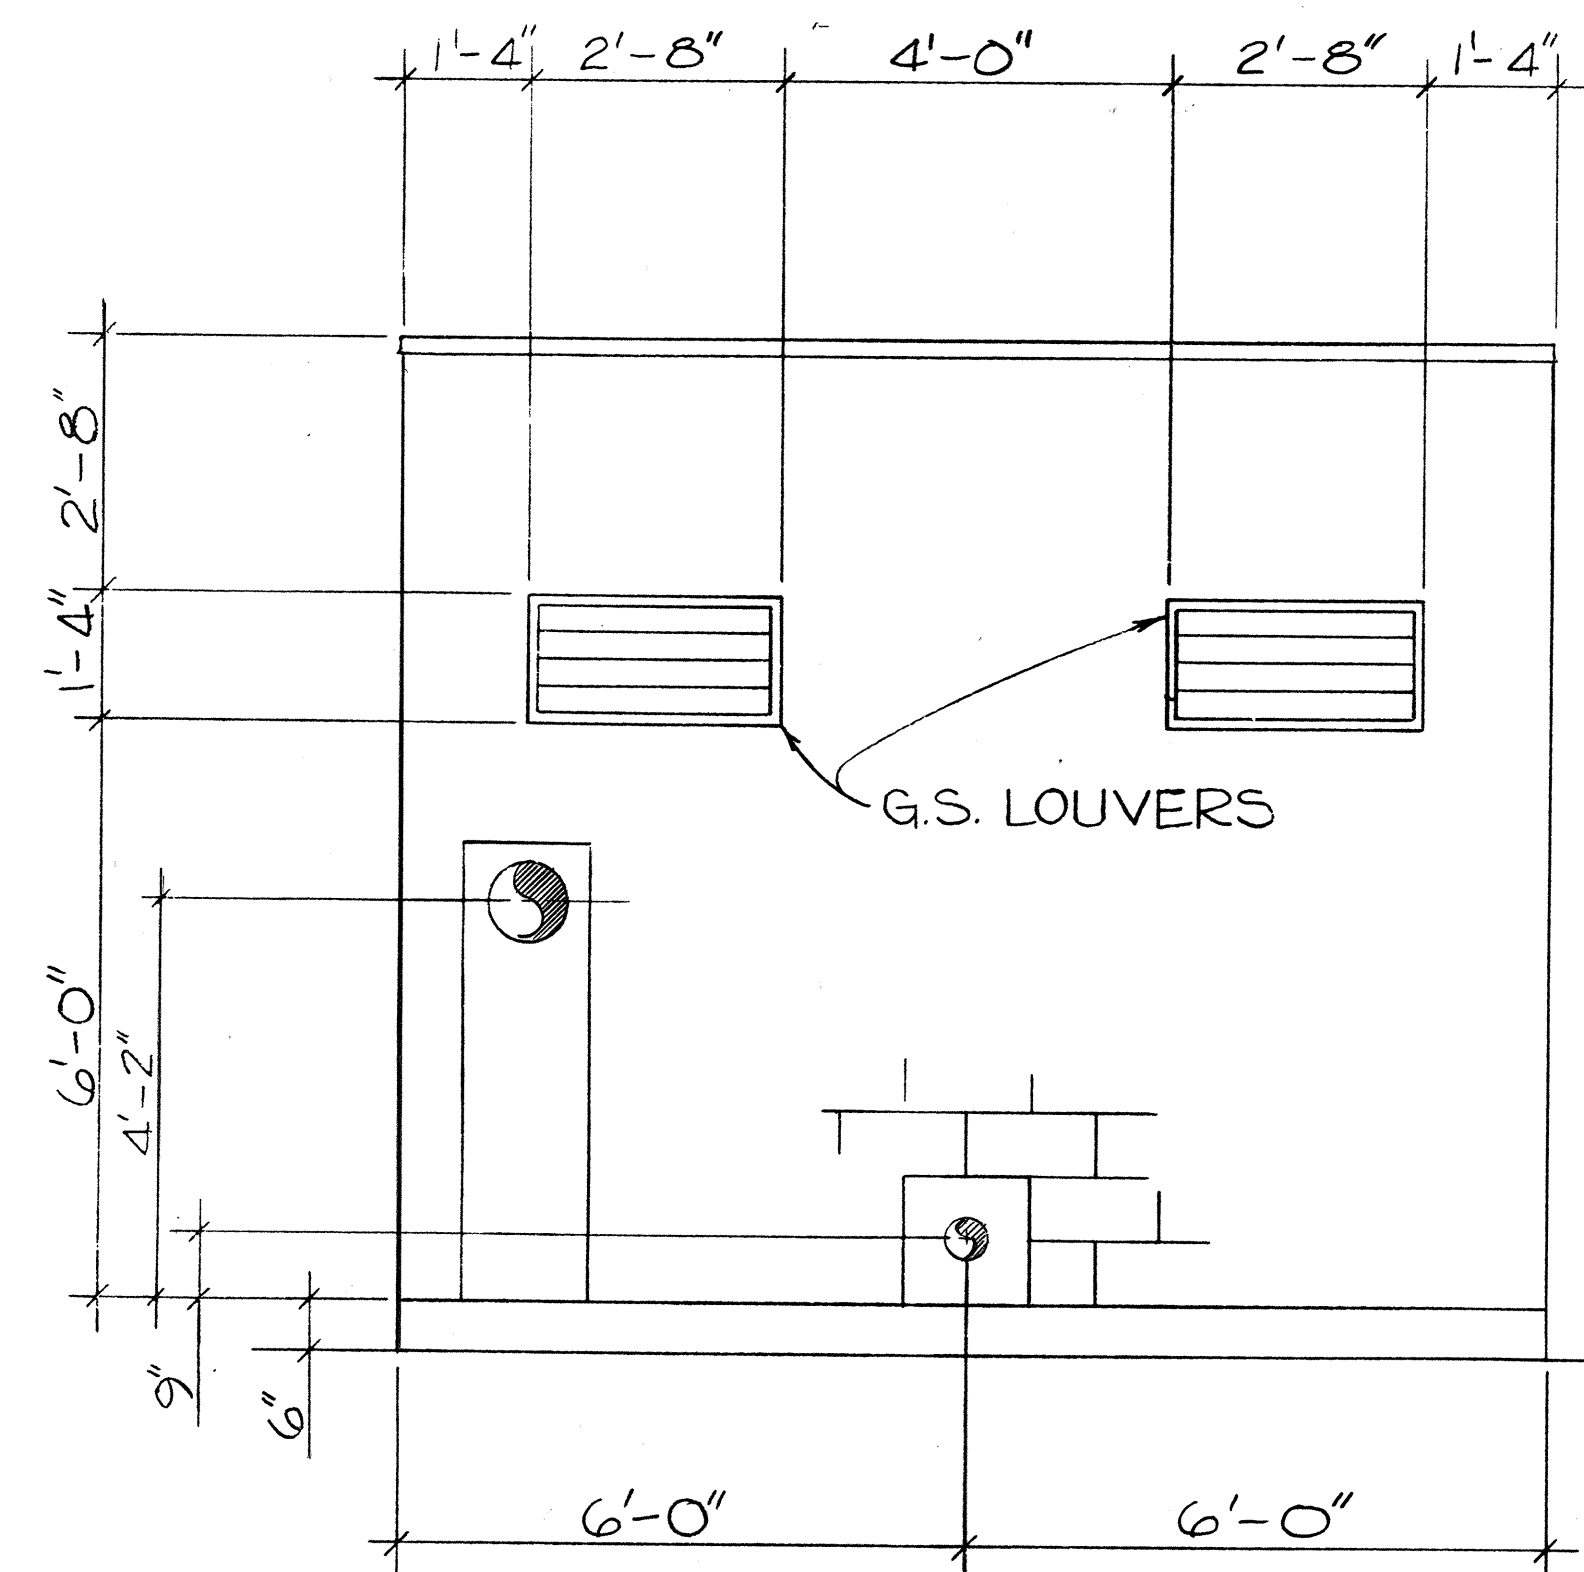


(G) 14 EXTERIOR EAST ELEVATION
SCALE 1/2" = 1'-0"

11/17/76 On Detail (Y) deleted part of reference to Flow Indicating Gauge per Addendum No. 1.


DATE REVISION

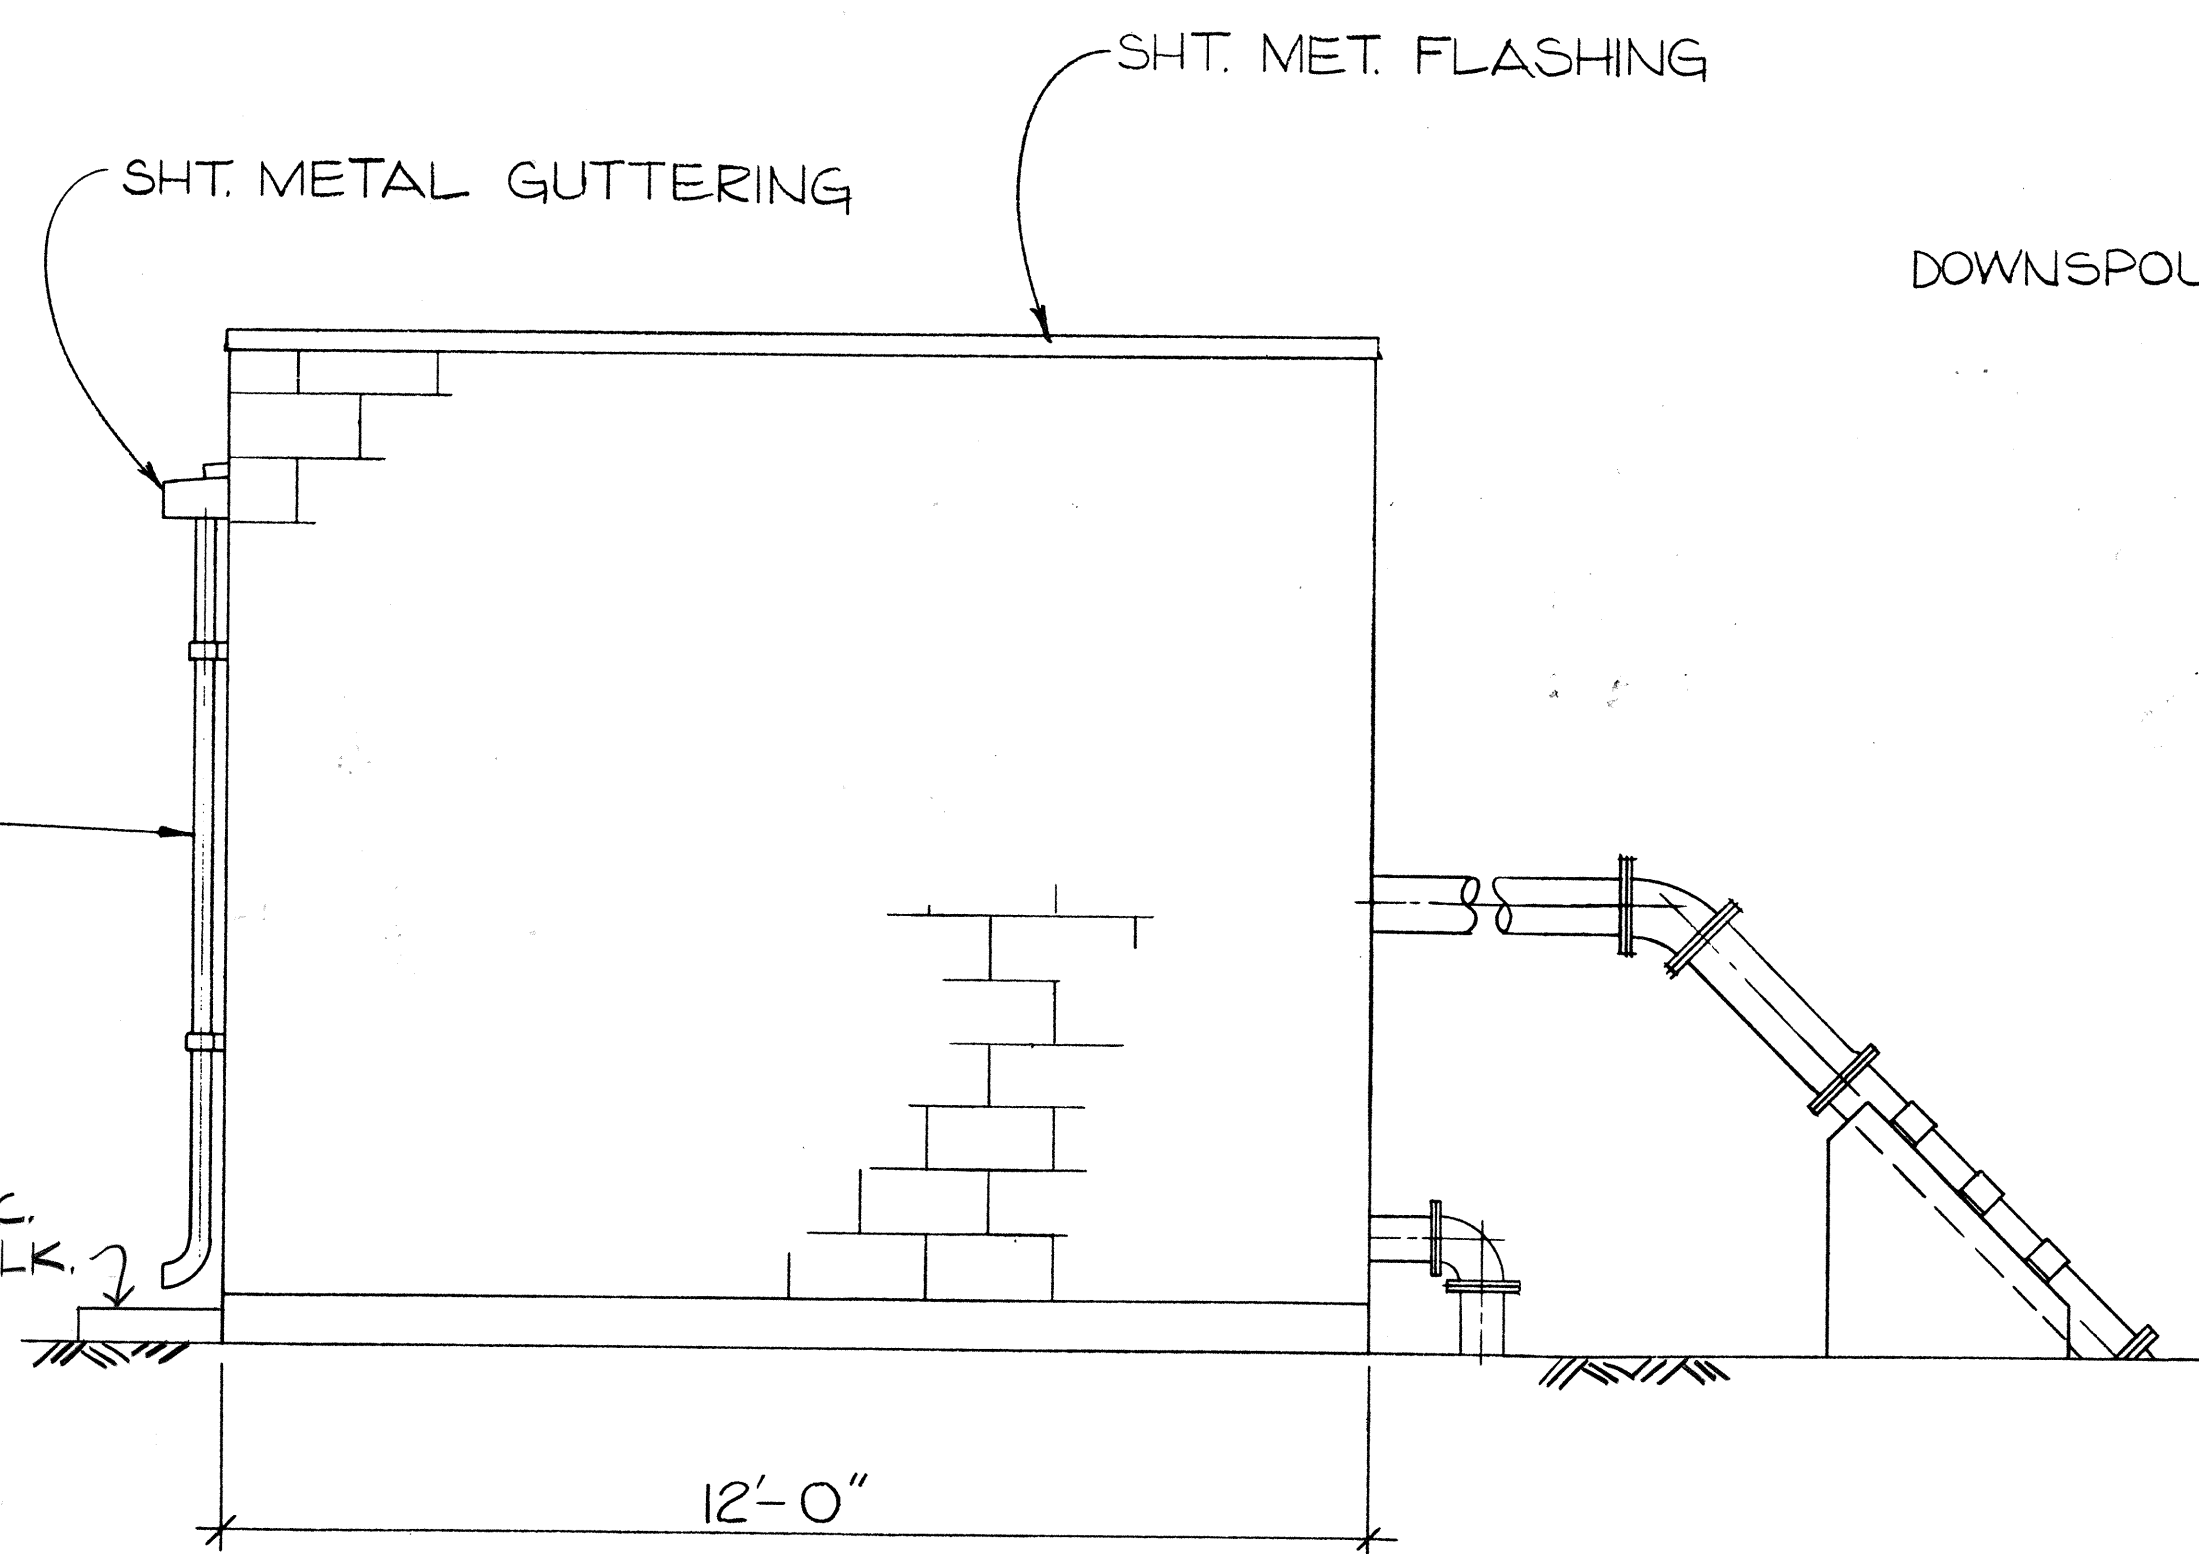

(F) 14 EXTERIOR SOUTH ELEVATION
SCALE 1/2" = 1'-0"
OPPOSITE FOR NORTH ELEV.

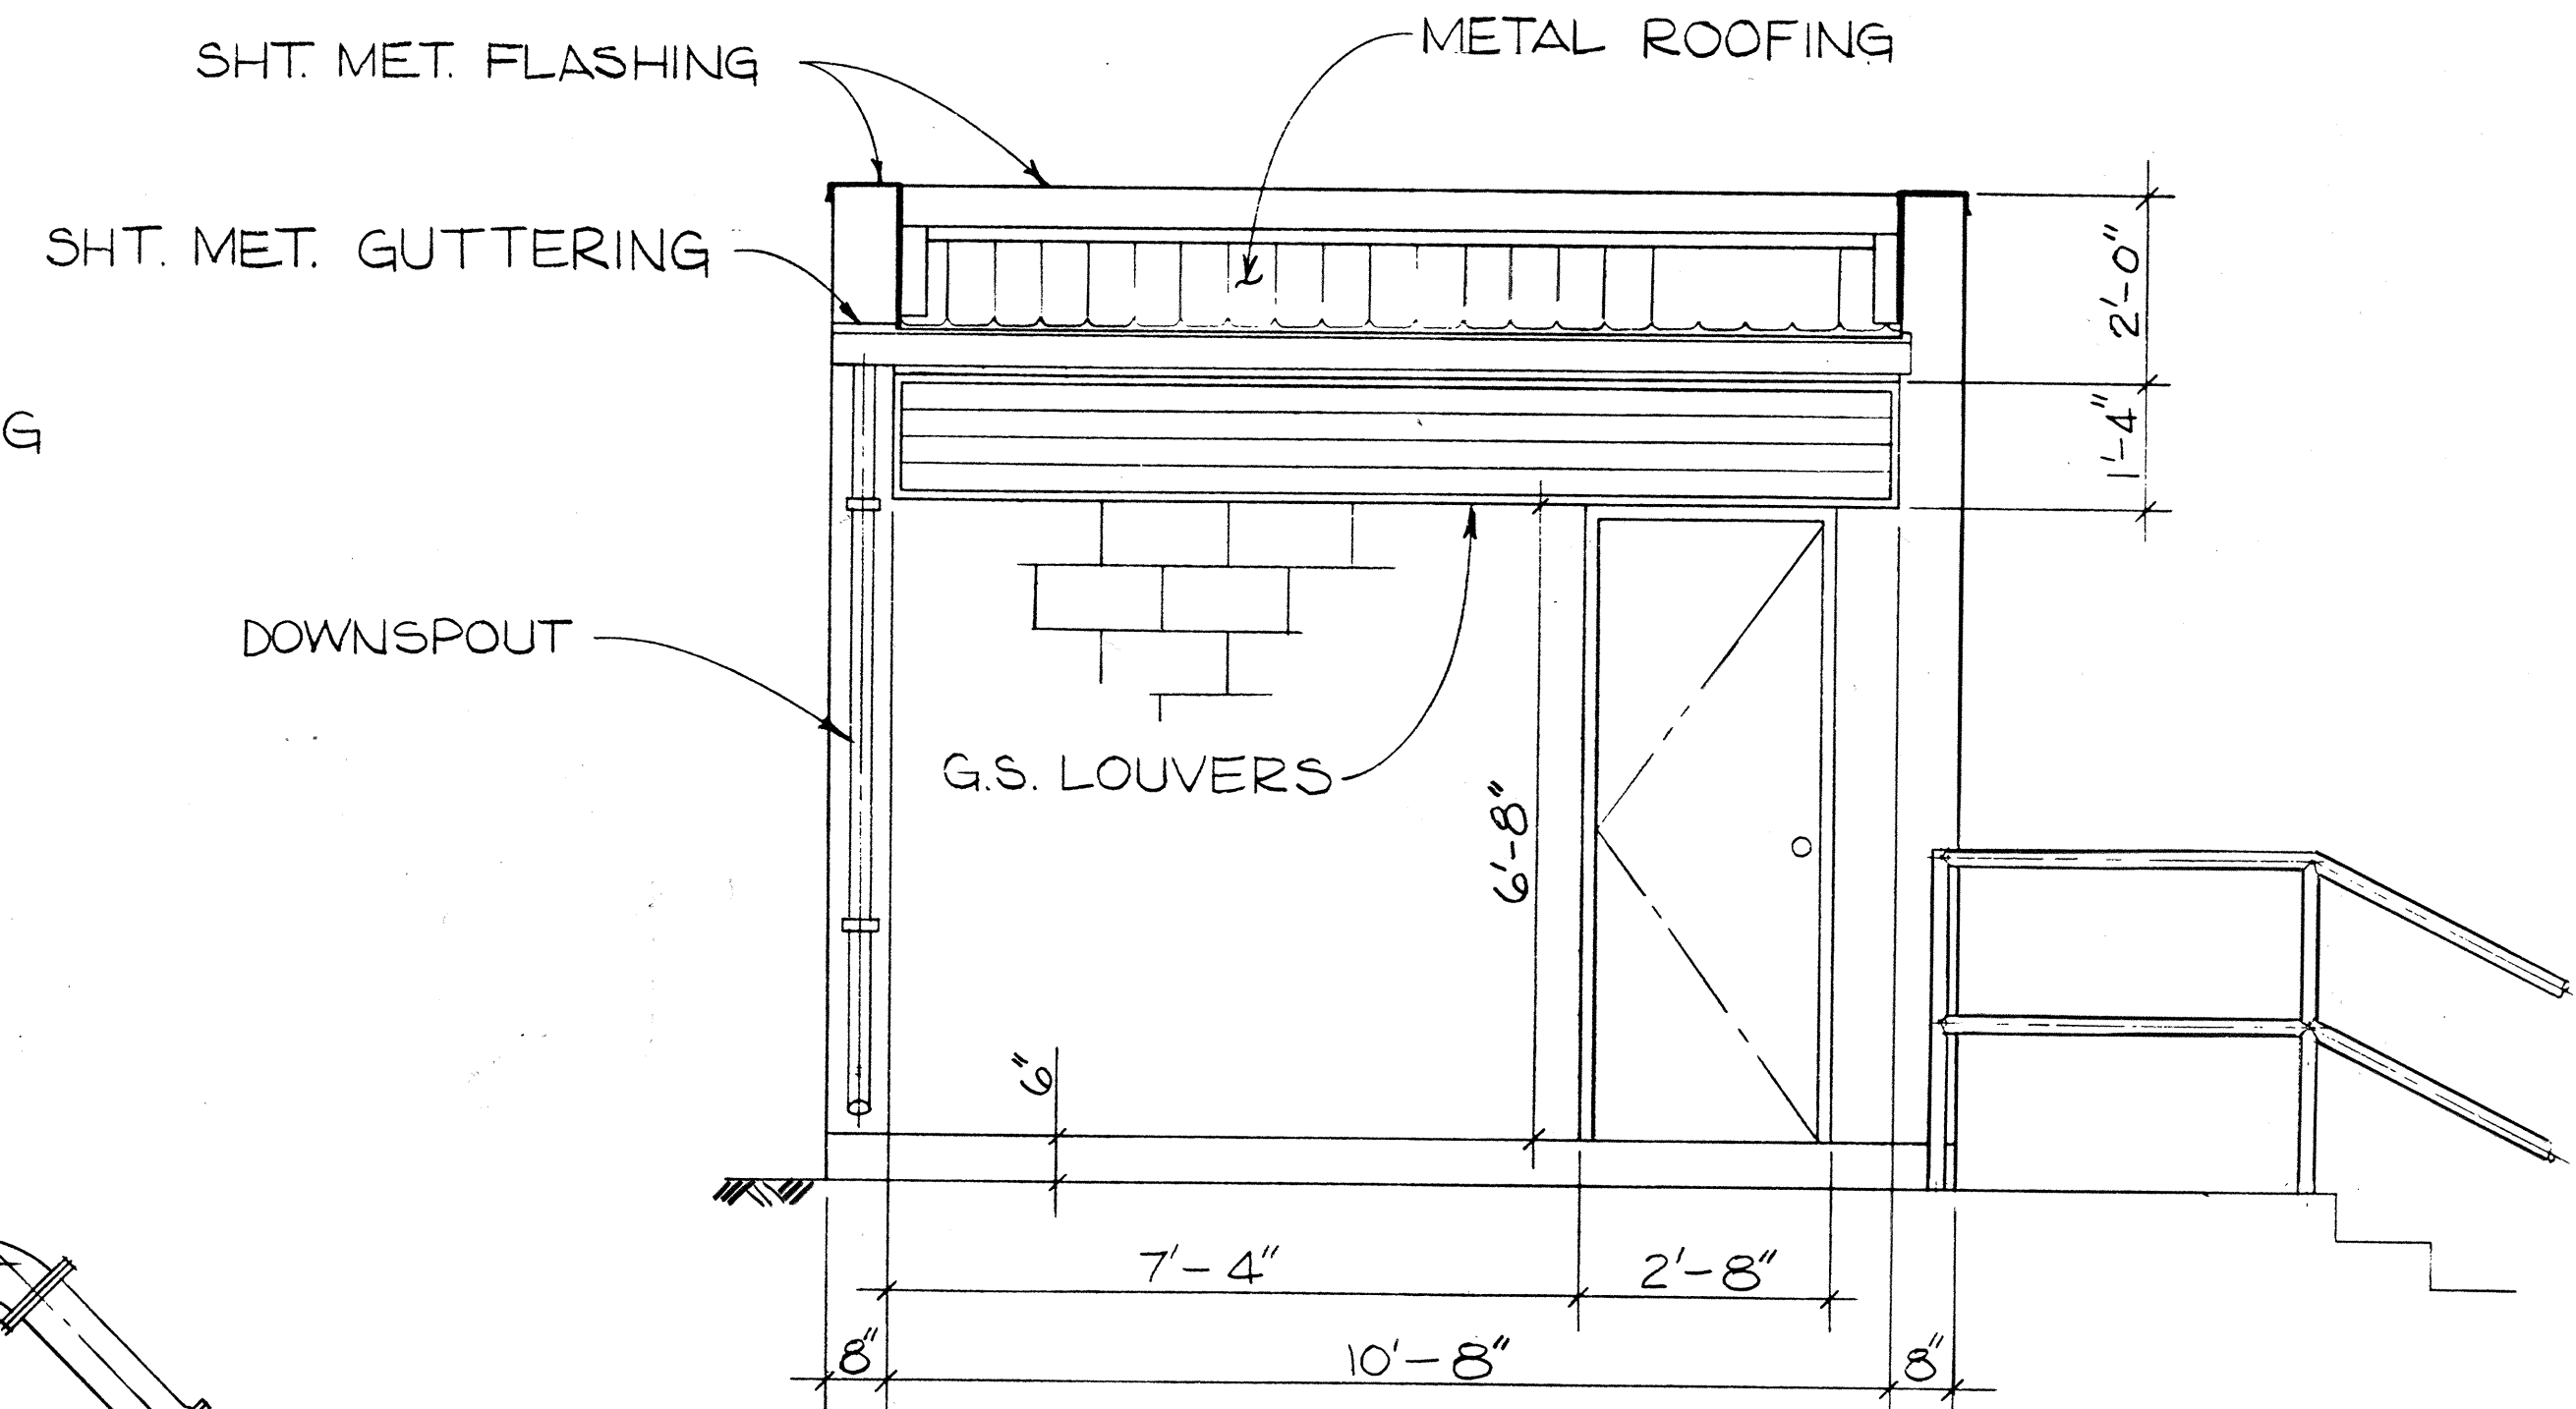

(E) 14 EXTERIOR WEST ELEVATION
SCALE 1/2" = 1'-0"

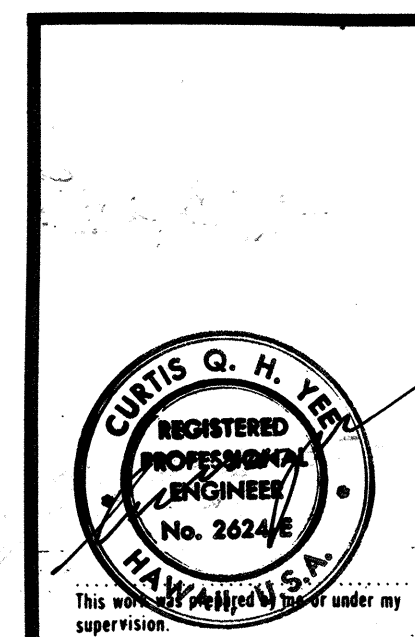


STATE OF HAWAII
DEPARTMENT OF TRANSPORTATION
HIGHWAYS DIVISION

PROJECT NO. I-H2-1(13):4







MILILANI INTERCHANGE
PUMP HOUSE
ELEVATIONS

SHEET No. 14 OF 25 SHEETS

FED. ROAD DIST. NO.	STATE	FED. AID PROJ. NO.	FISCAL YEAR	SHEET NO.	TOTAL SHEETS
HAWAII	HAW.	I-H2-1(13):4	1977	24	34

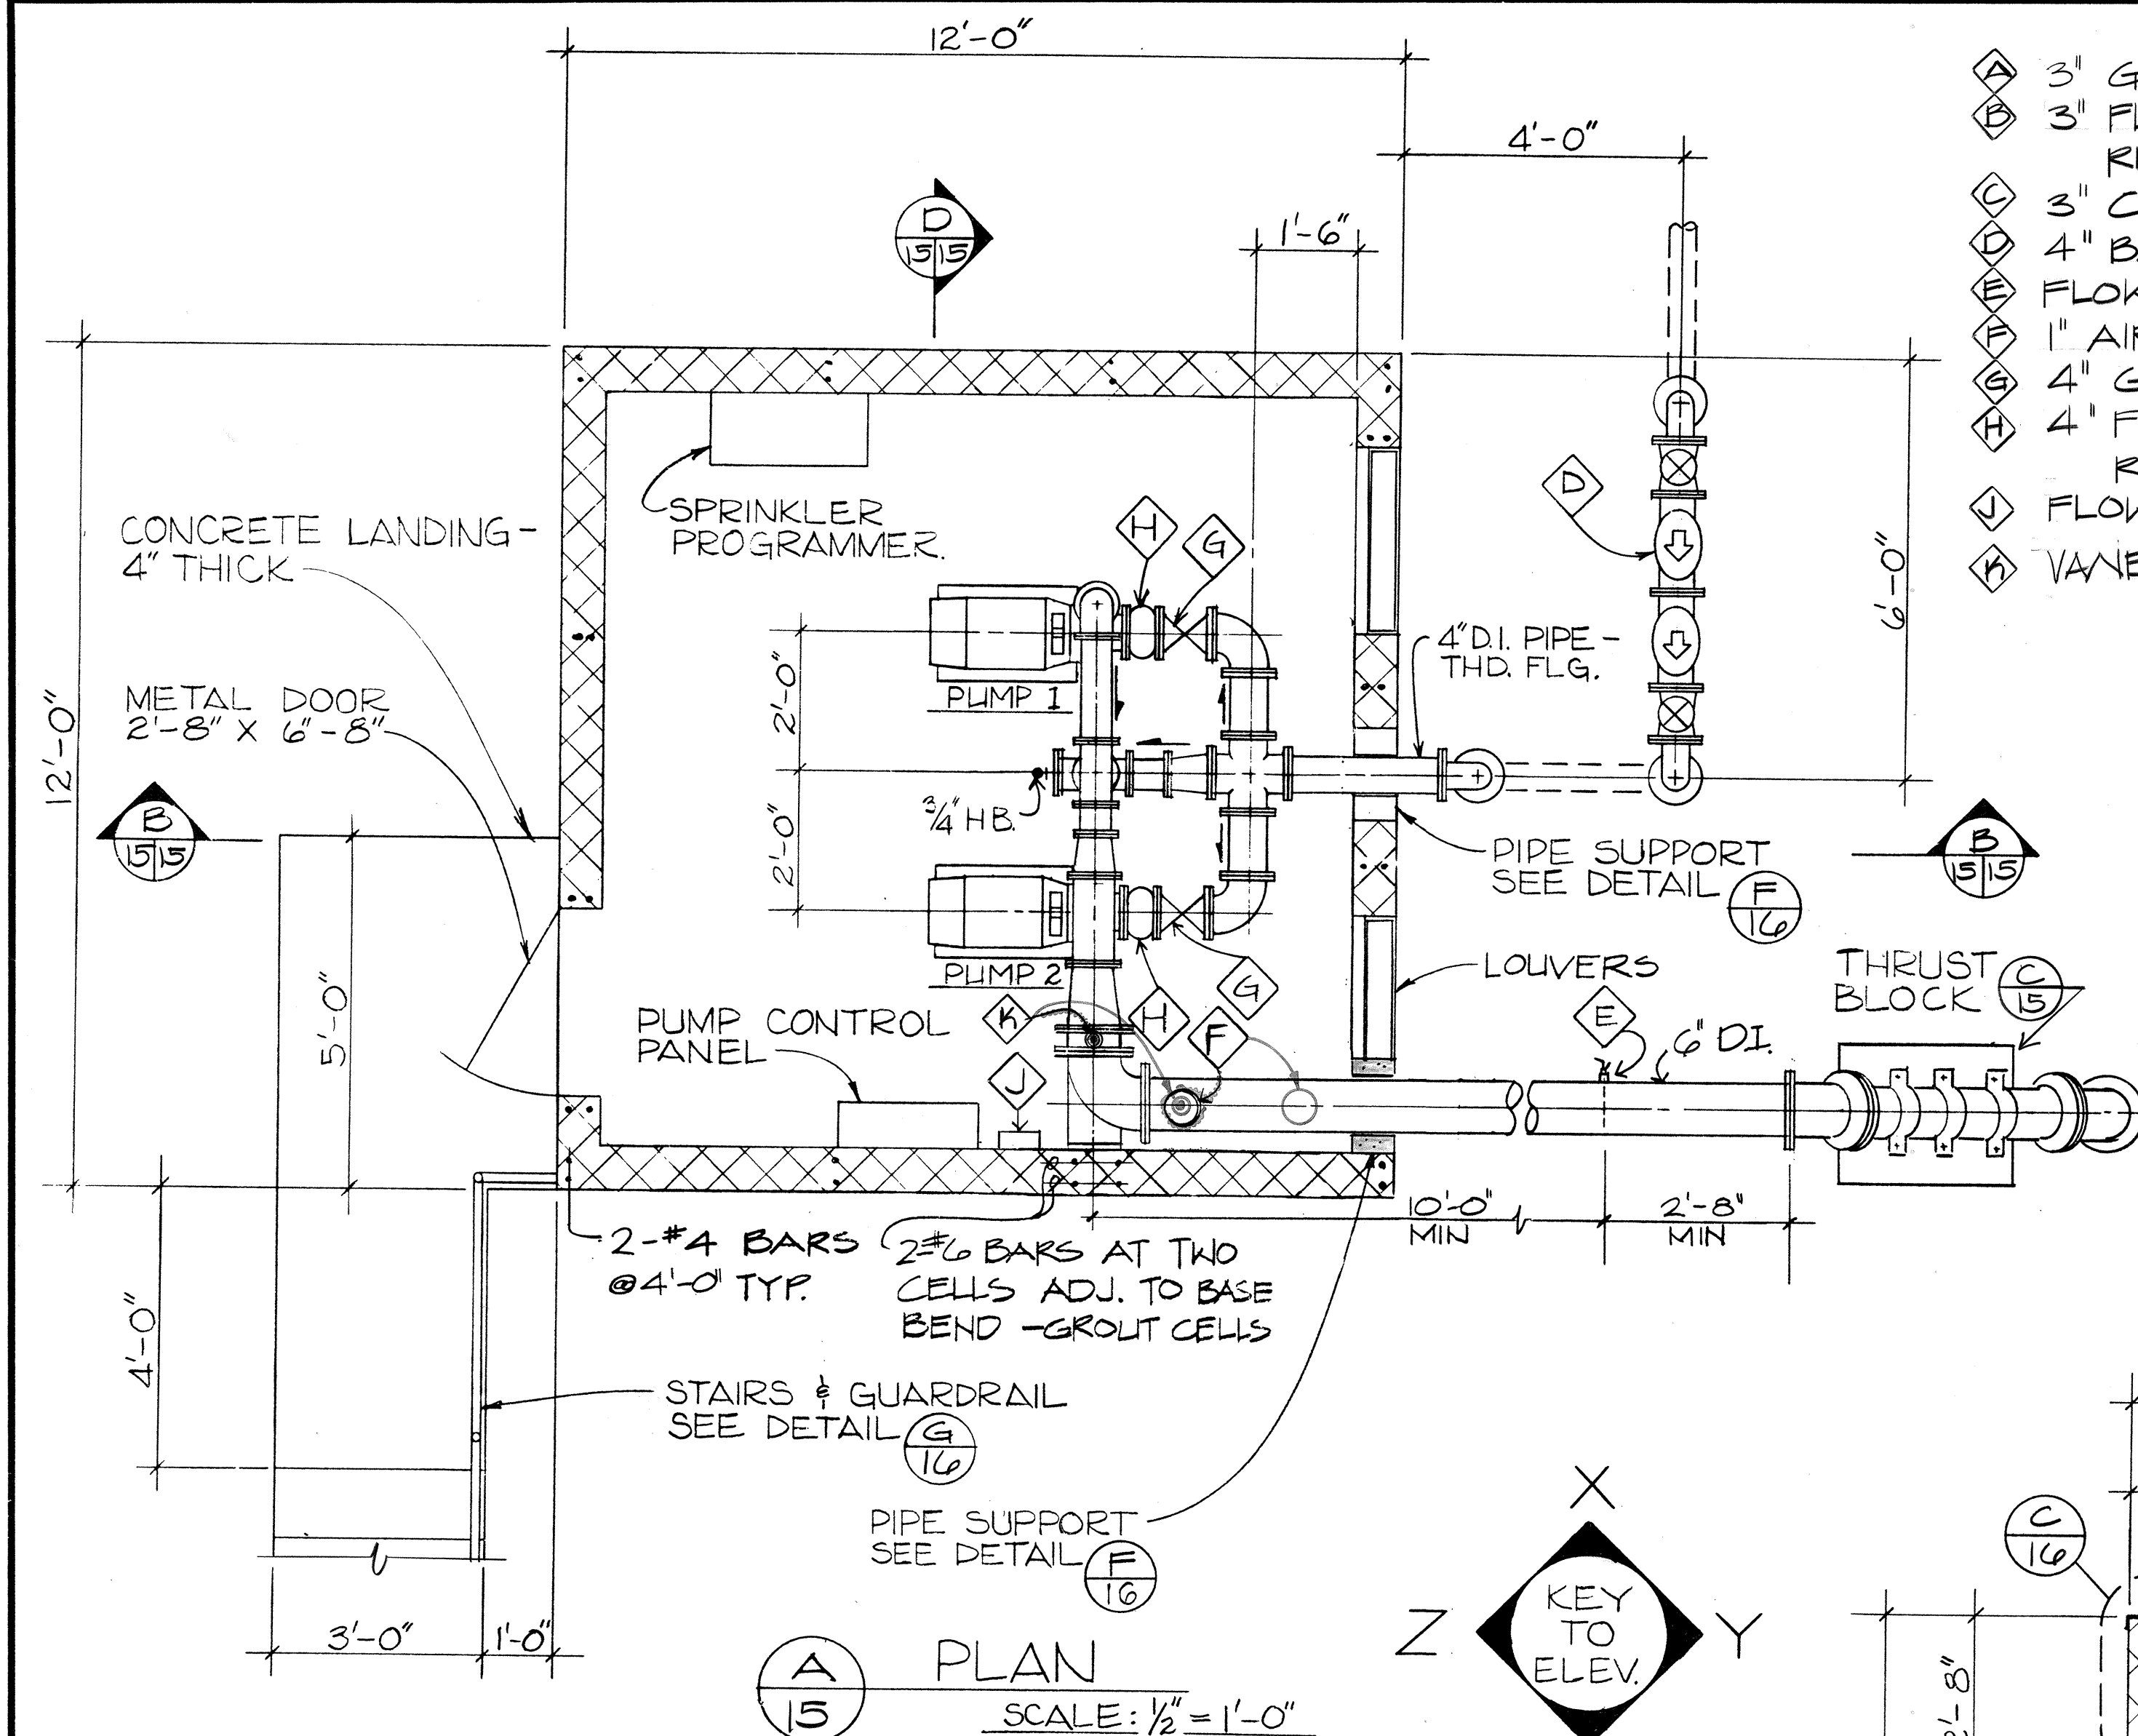

- (A) 3" GATE VALVE
- (B) 3" FLEXIBLE SPHERE-TYPE REINF. RUBBER CONNECTOR
- (C) 3" CHECK VALVE
- (D) 4" BACKFLOW PREVENTER
- (E) FLOW MEASURING ELEMENT
- (F) 1" AIR RELEASE VALVE
- (G) 4" GATE VALVE
- (H) 4" FLEXIBLE SPHERE-TYPE REINF. RUBBER CONNECTOR
- (I) FLOW INDICATING GAUGE W/CONTACT
- (J) VANE-TYPE FLOW SWITCH

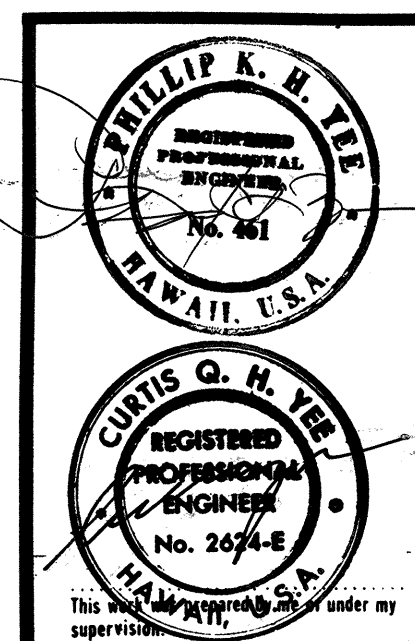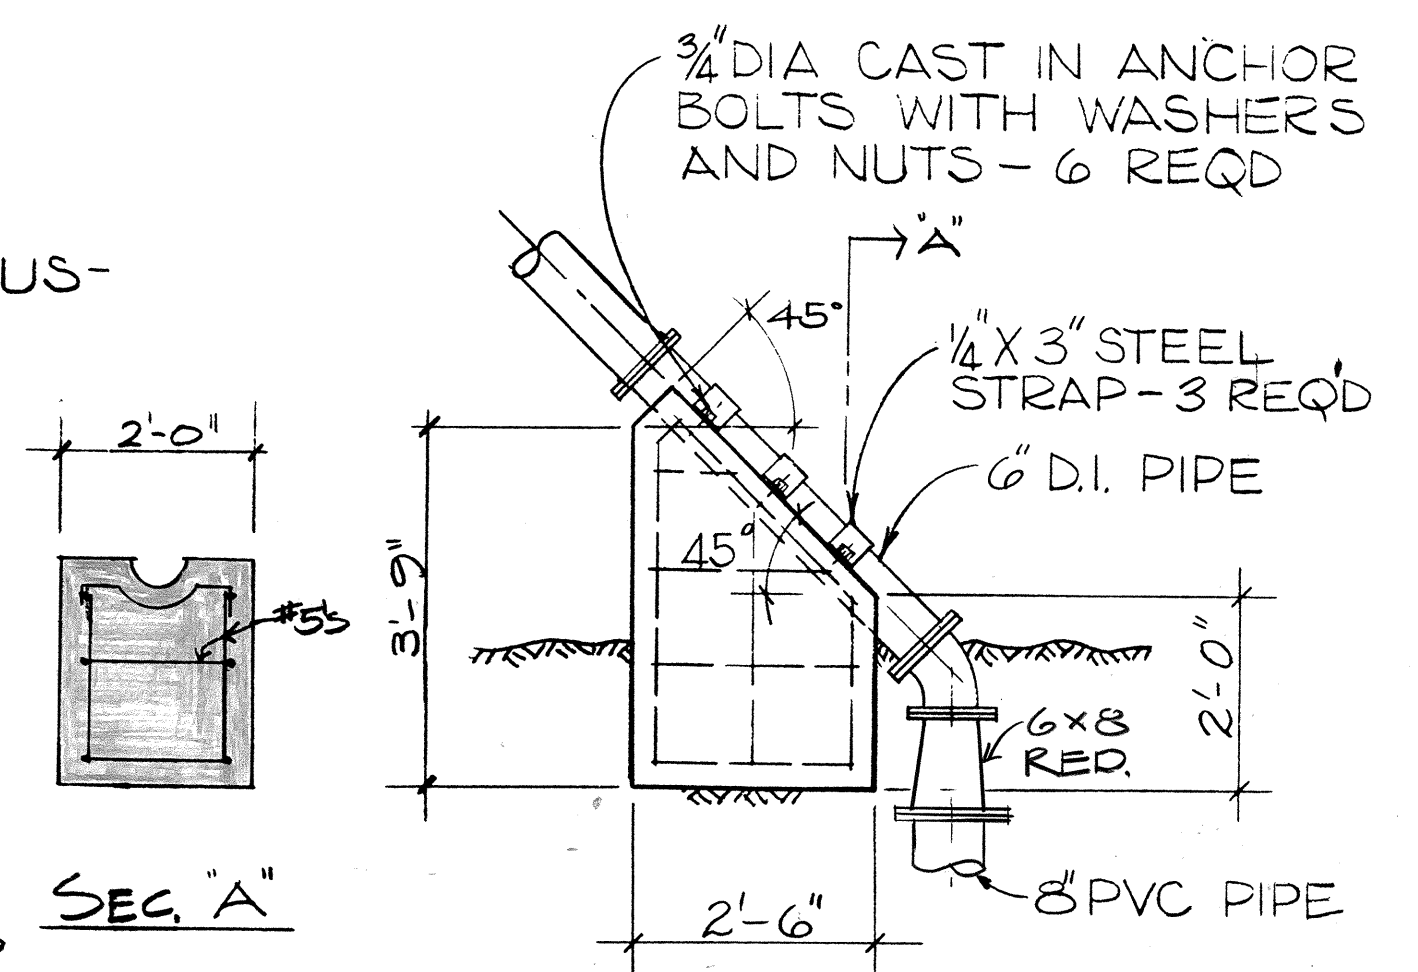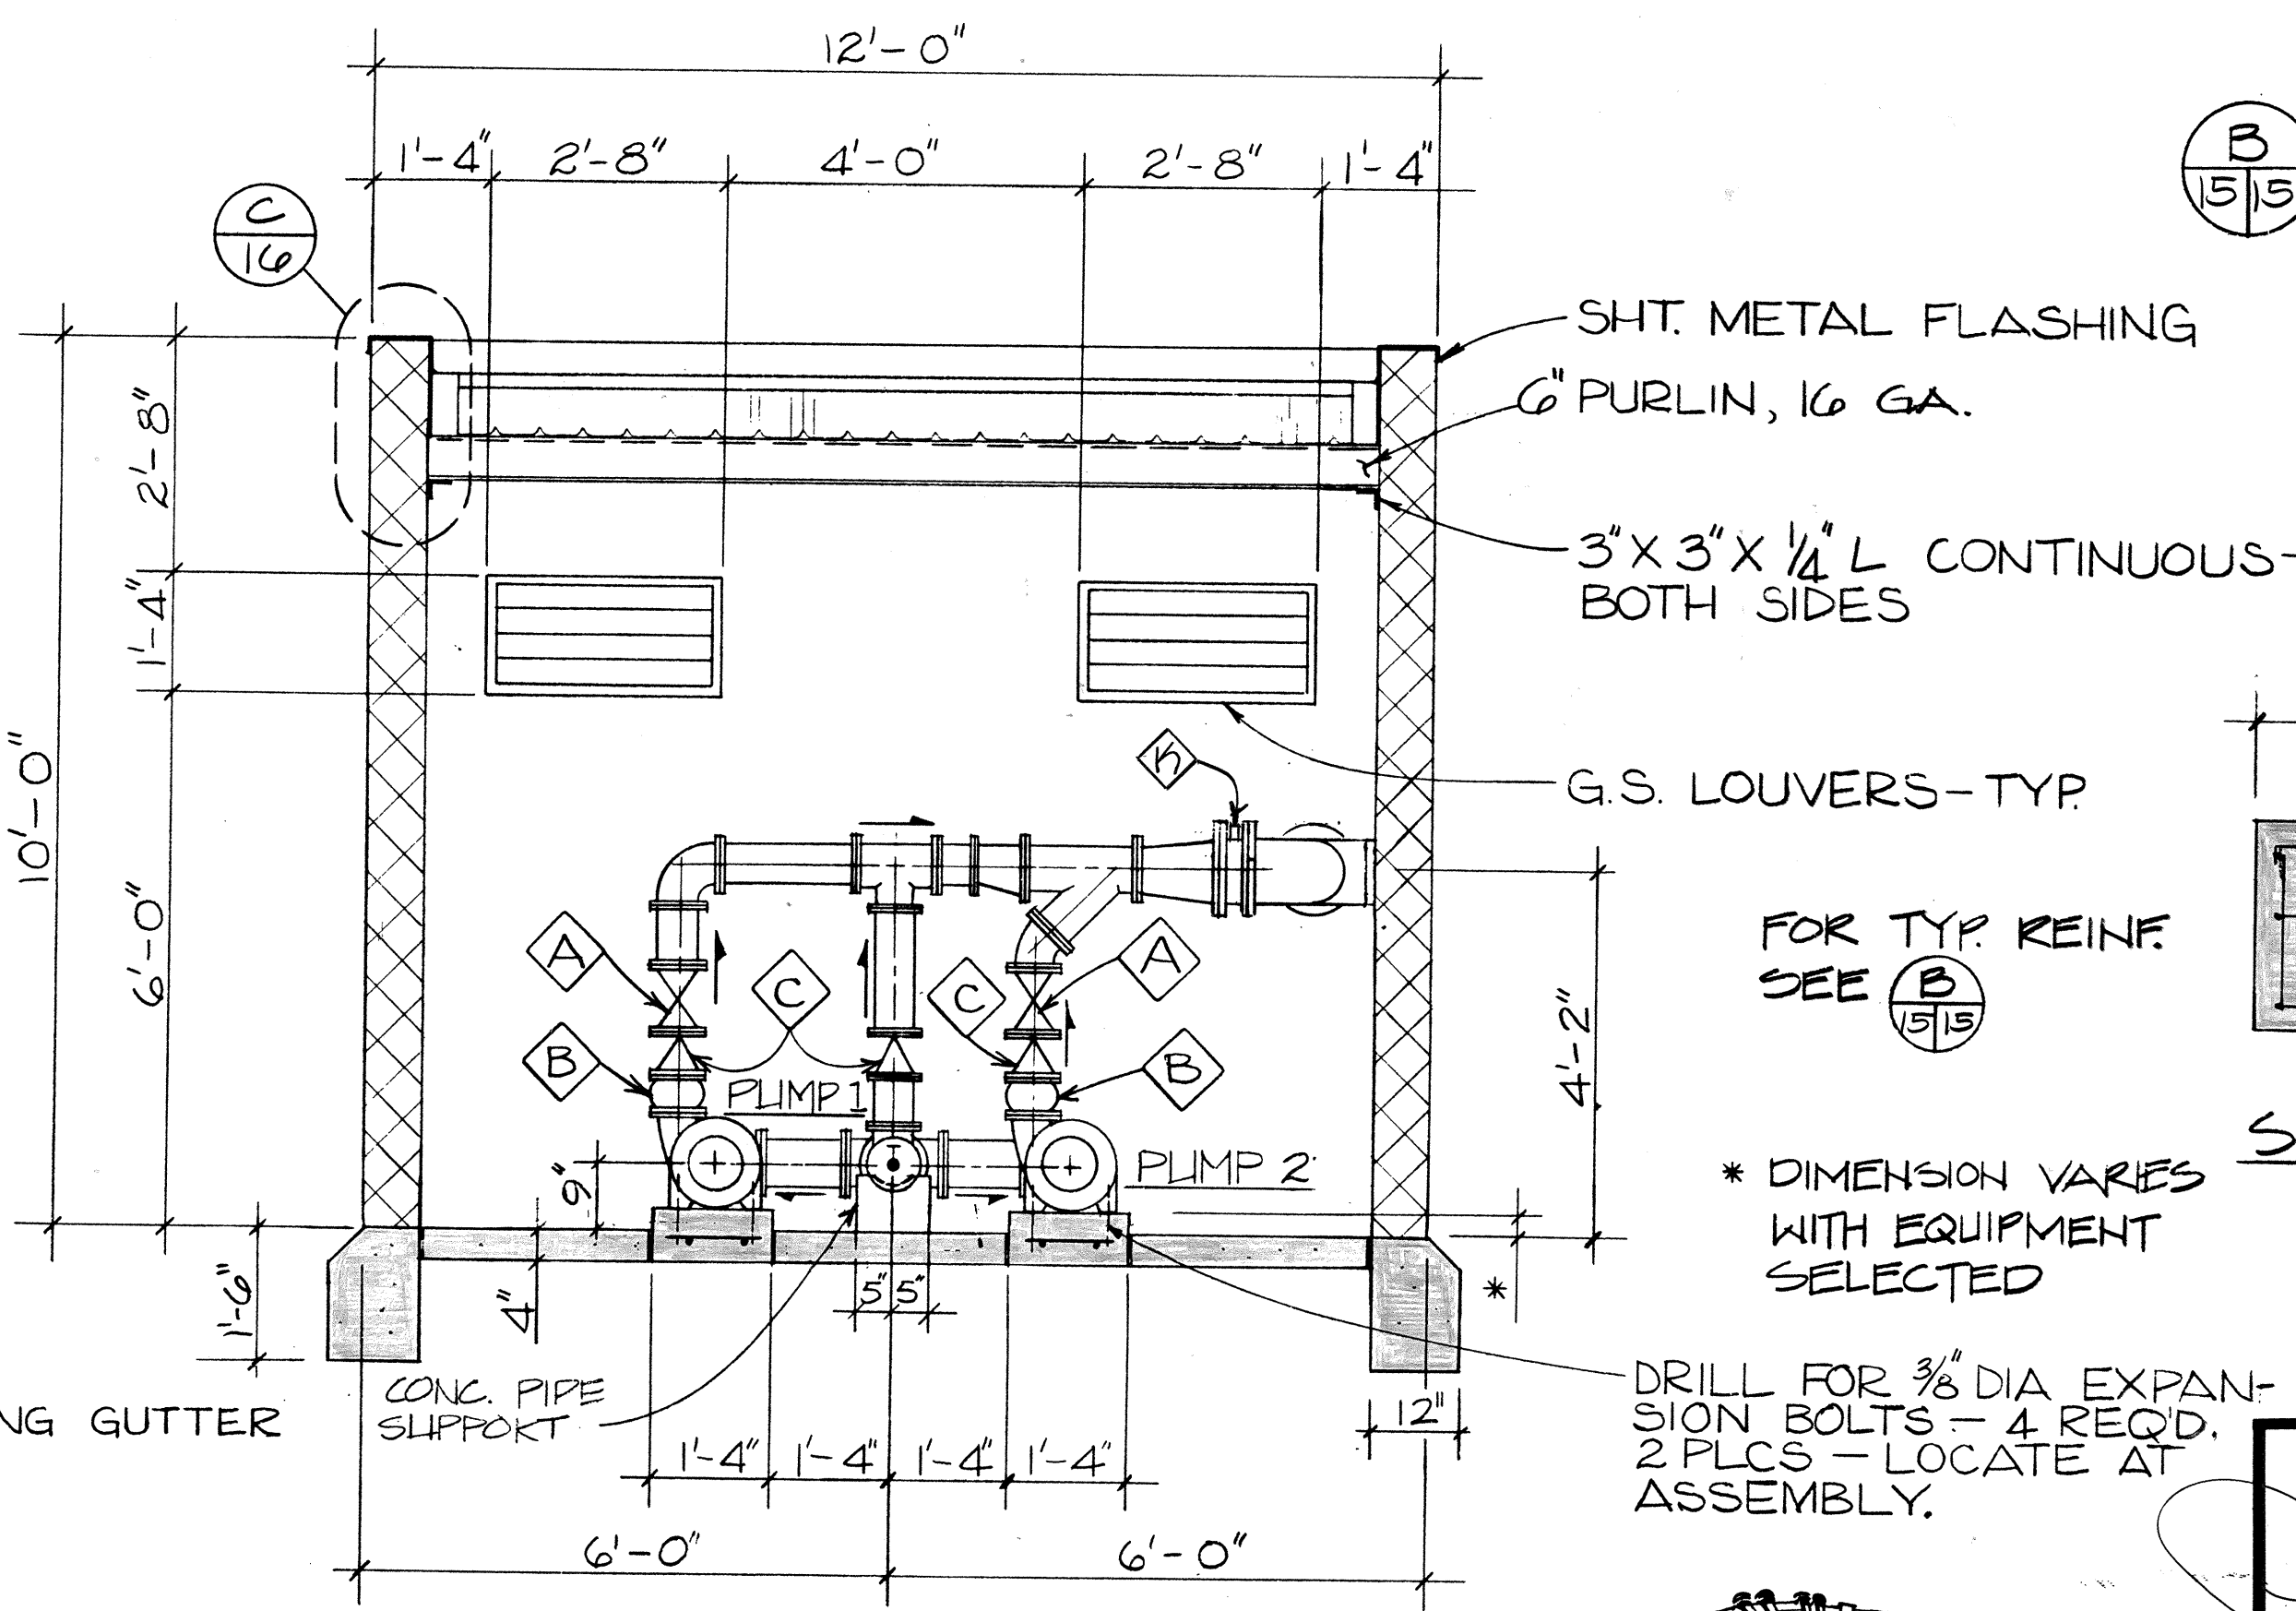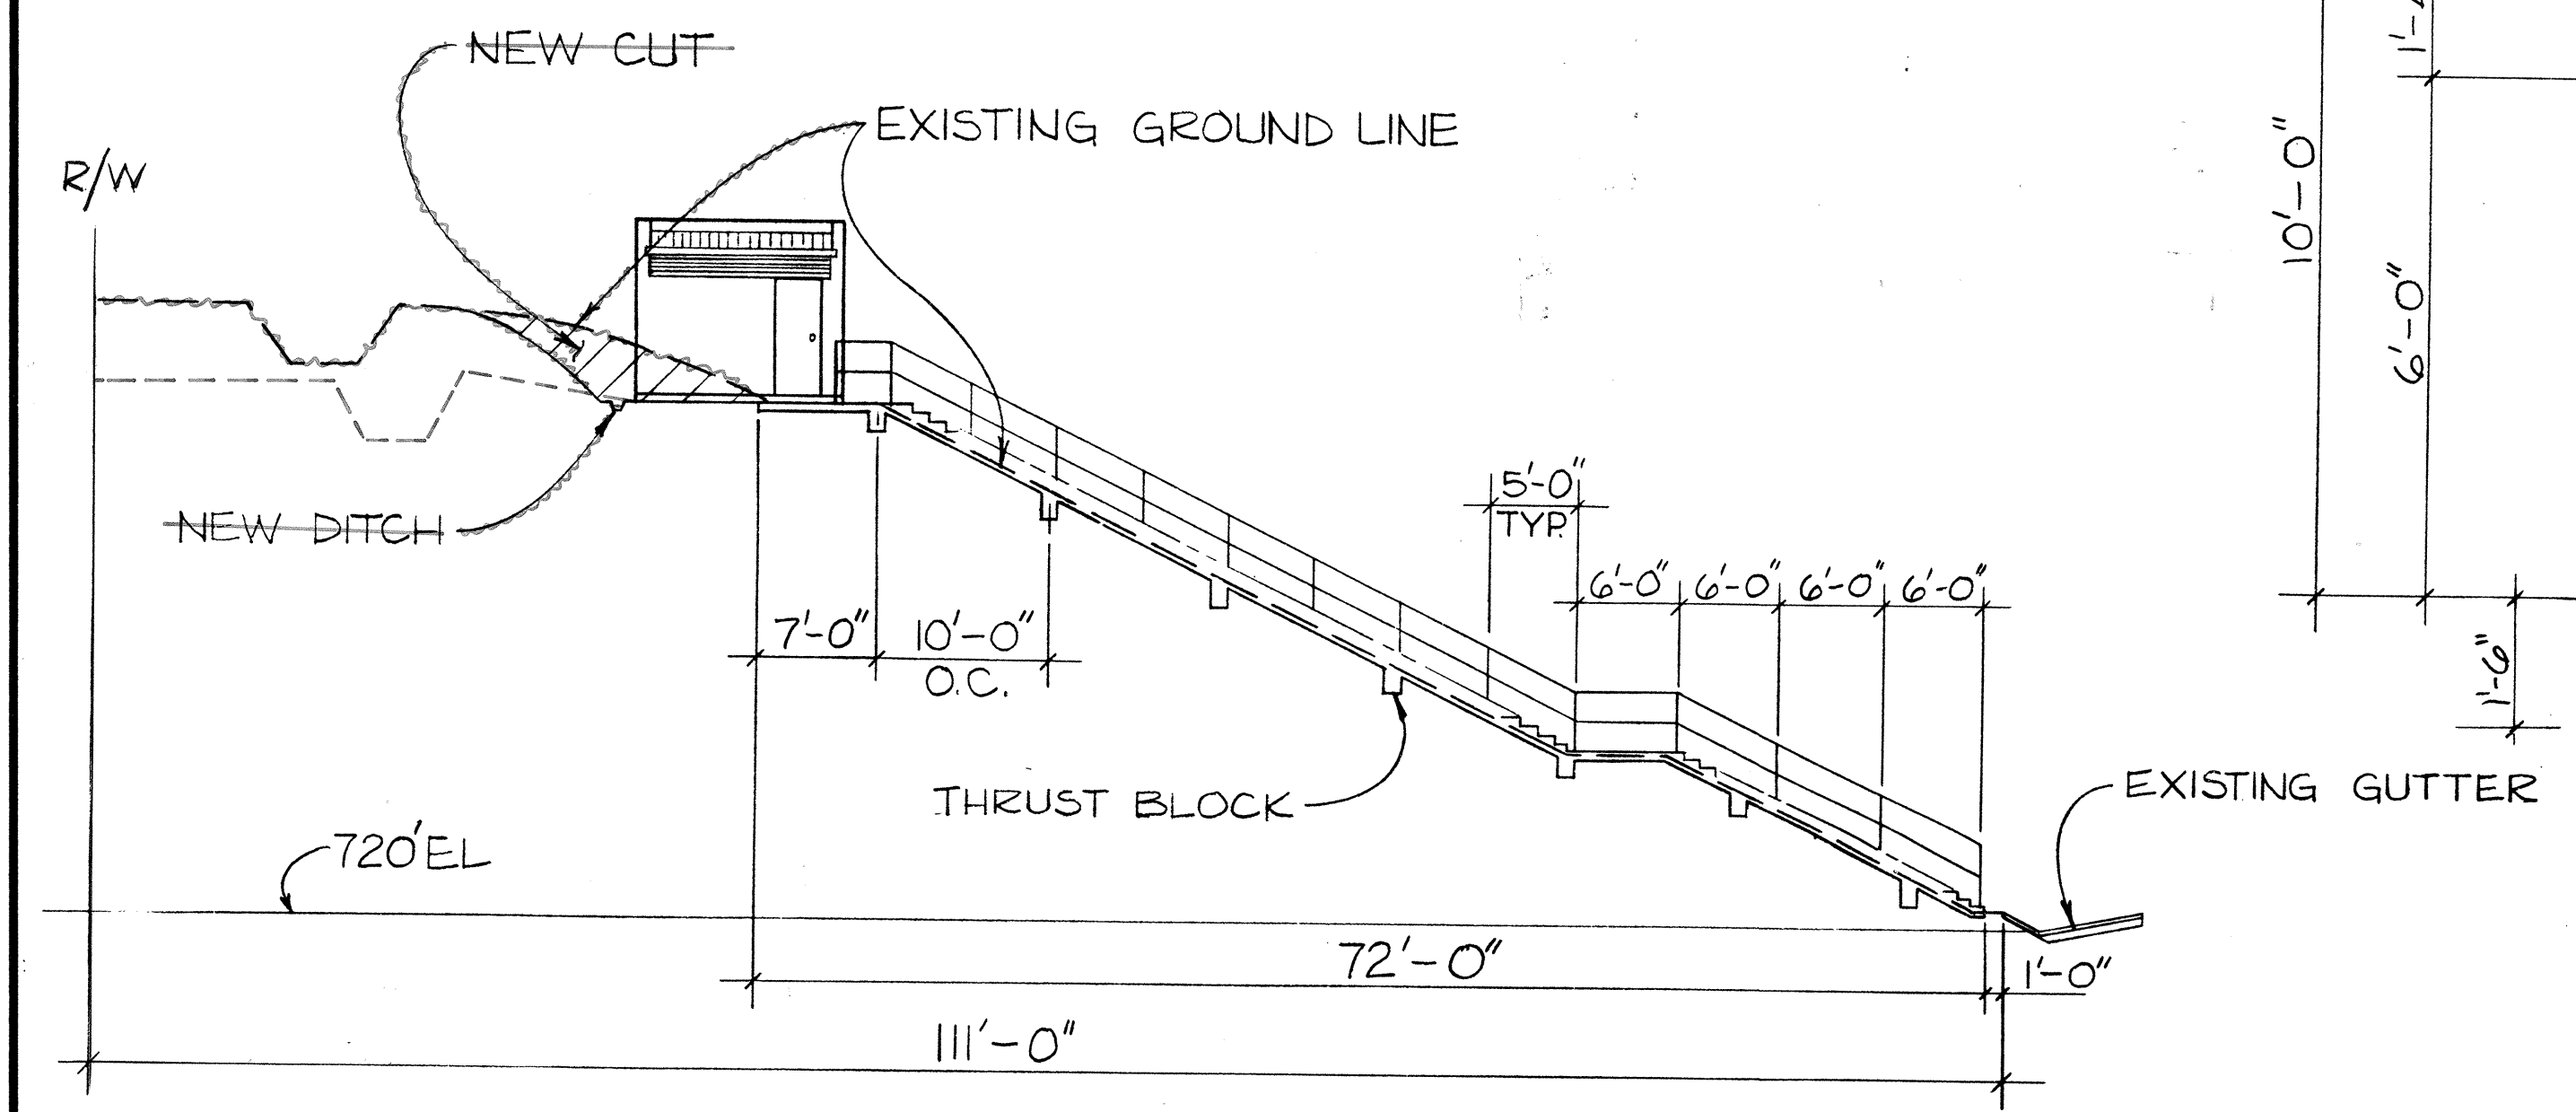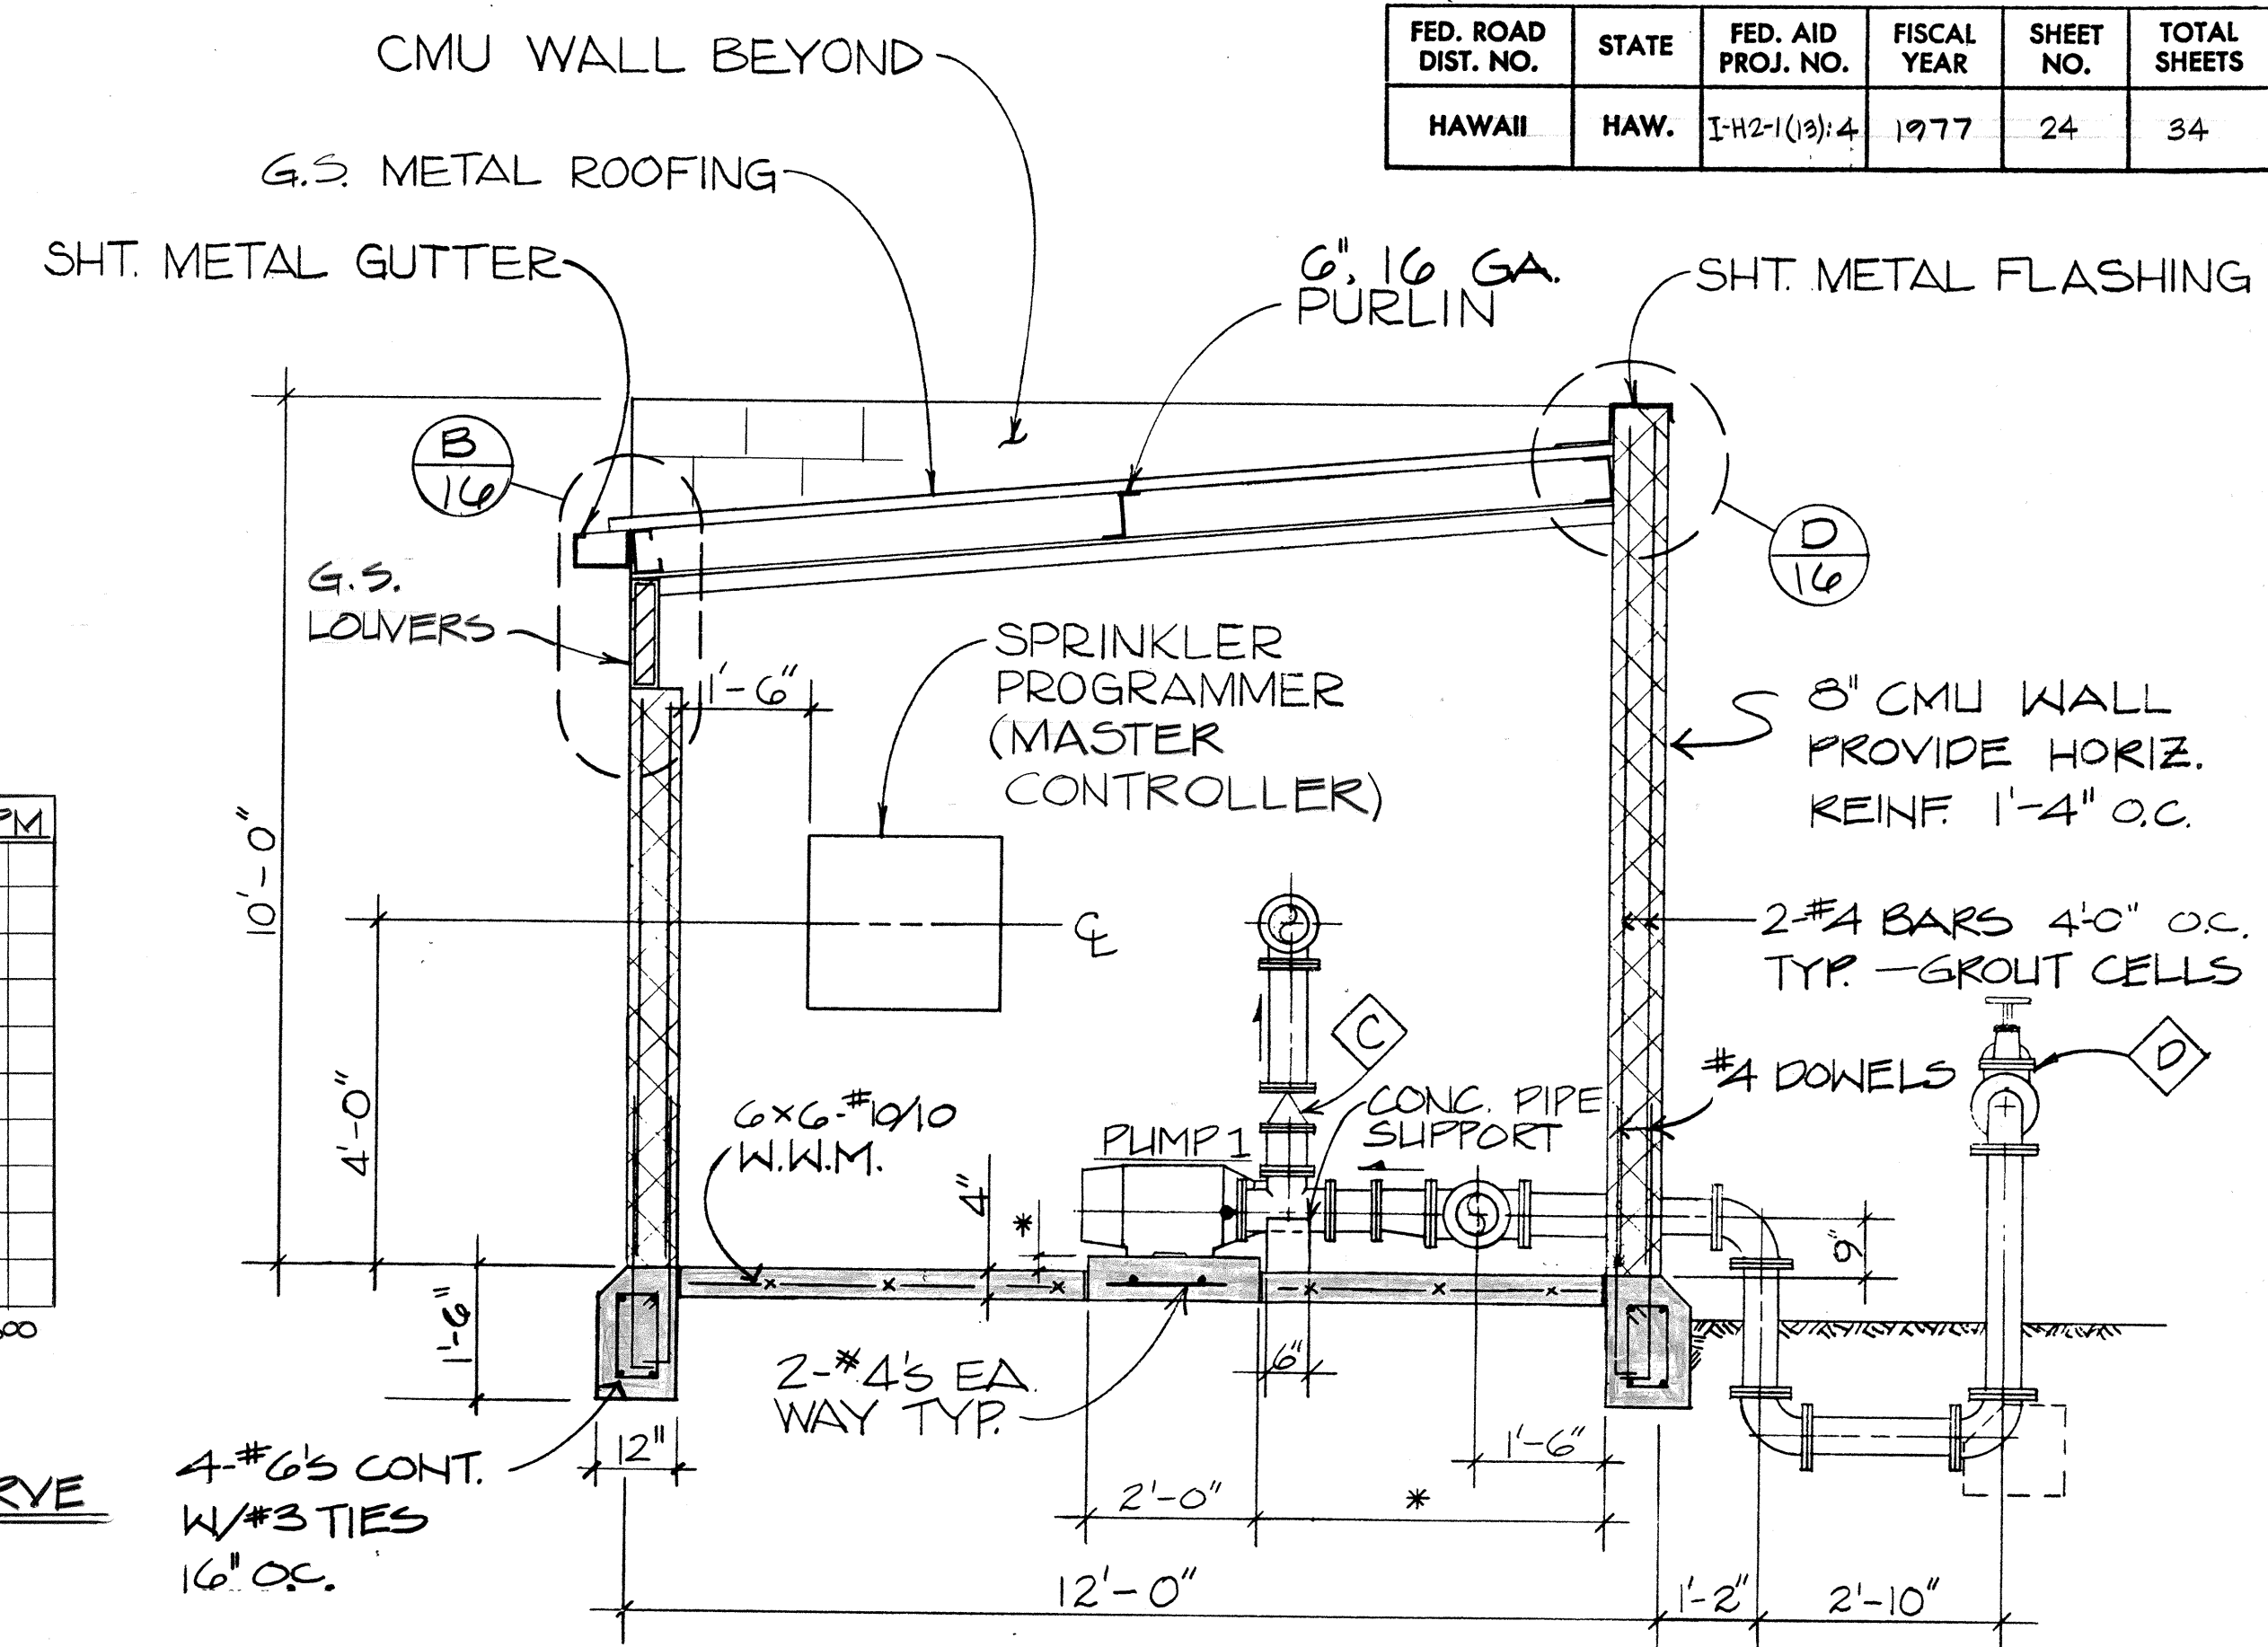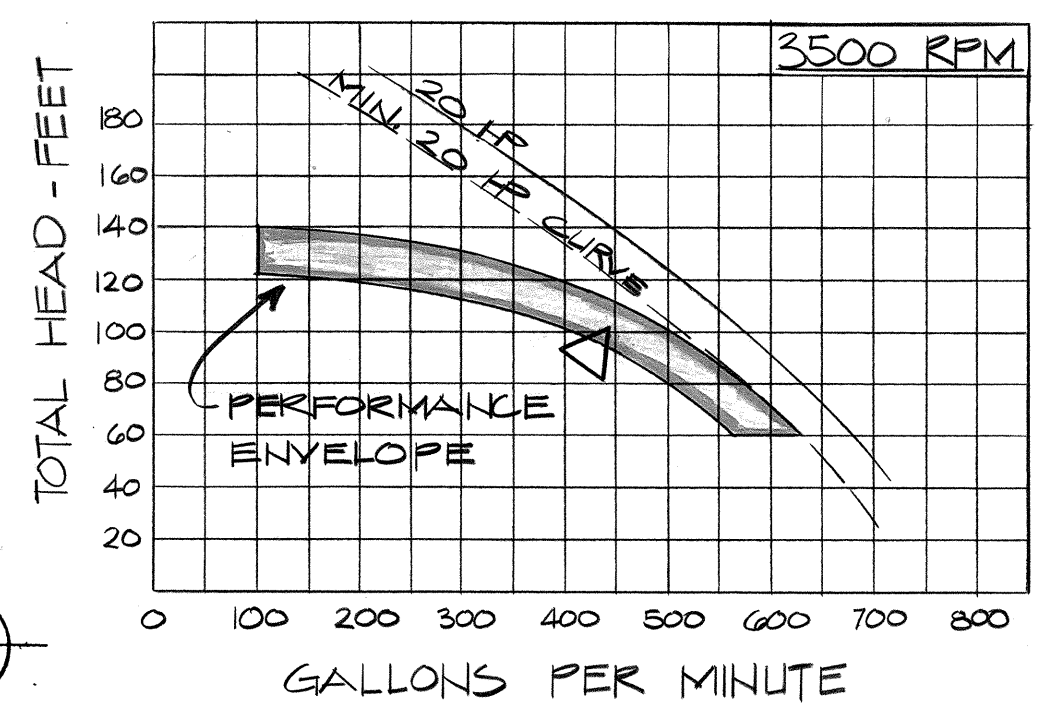

STATE OF HAWAII
DEPARTMENT OF TRANSPORTATION
HIGHWAYS DIVISION

PROJECT NO. I-H2-1(13):4

MILILANI INTERCHANGE
PUMP HOUSE
SECTIONS


SHEET No. 15 OF 25 SHEETS

DATE	11/17/76
DESIGNED BY	PHILLIP A. H. LEE
DRAWN BY	PHILLIP A. H. LEE
CHECKED BY	PHILLIP A. H. LEE
NOTED BY	PHILLIP A. H. LEE
NO.	1

DATE	11/17/76
REVISION	Pipe Support reference circle on Detail (F) 16 to read (F) 16.


NOTE:

ALL PIPING SHOWN SHALL BE OF DUCTILE IRON CONSTRUCTION UNLESS OTHERWISE SPECIFIED.

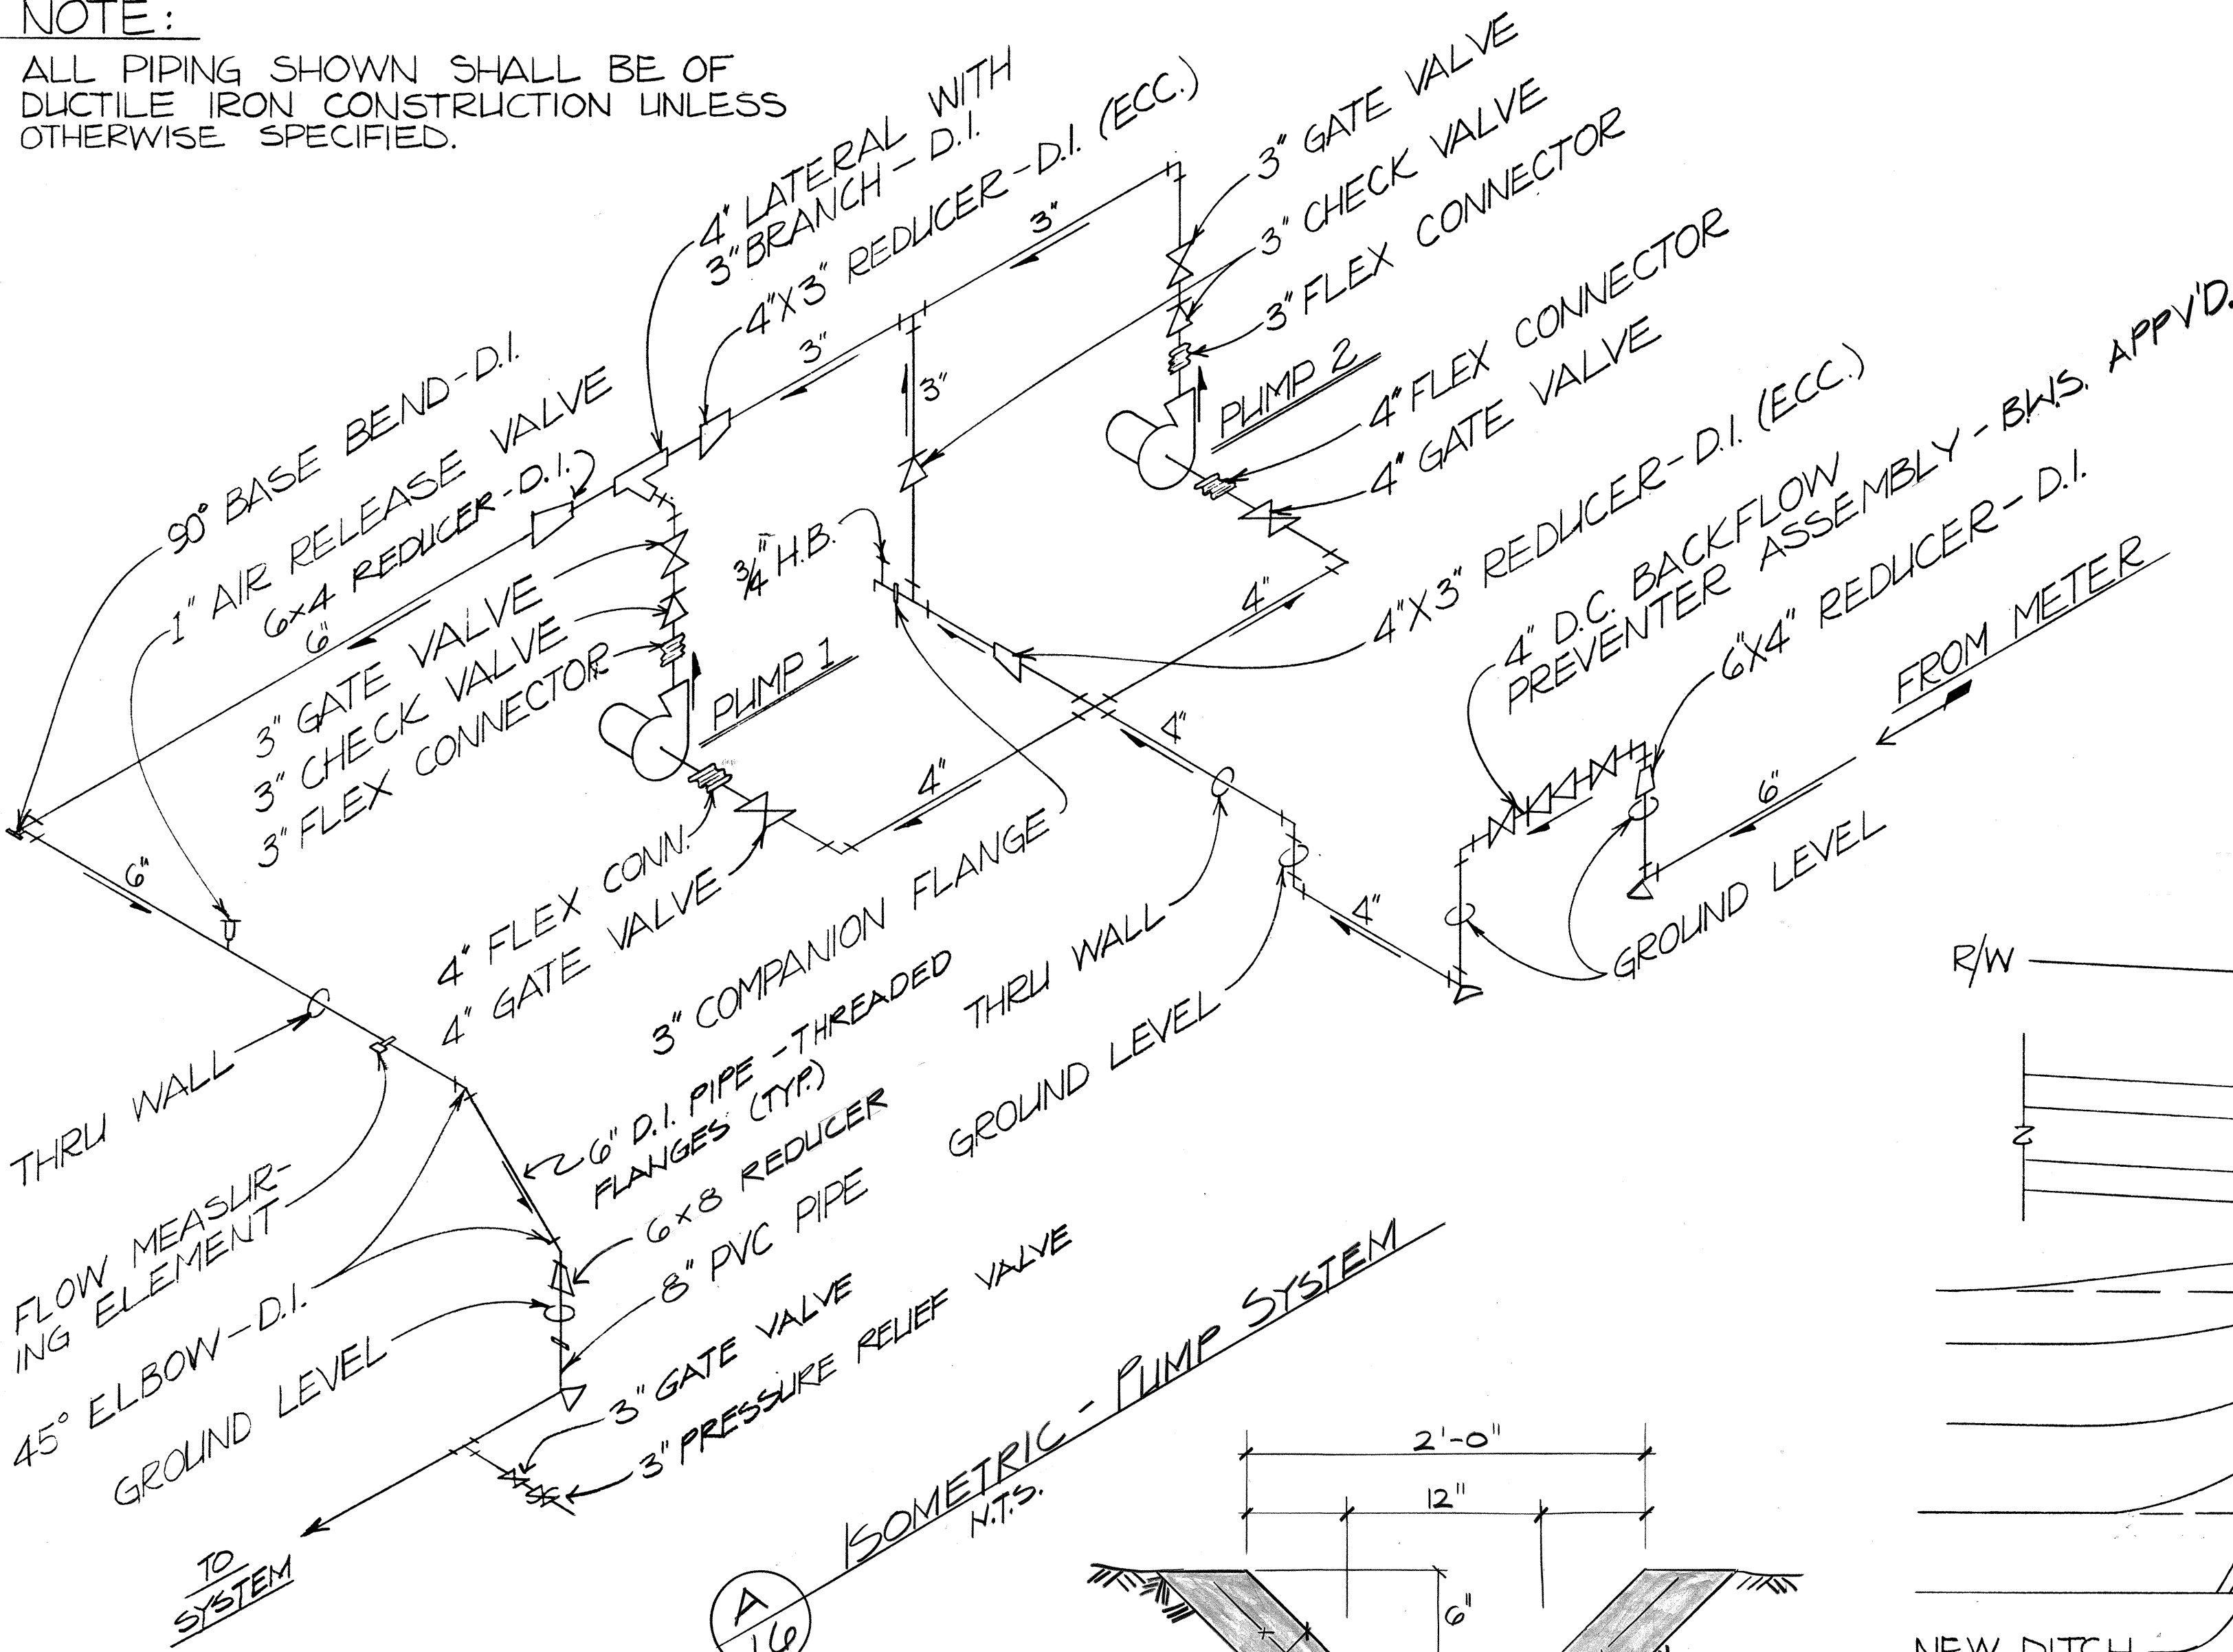


NOTE:


ALL JOINTS SHALL BE WELDED, GROUND, AND COATED WITH TWO COATS OF ZRC. ENTIRE RAILING SHALL BE PAINTED W/2 COATS OF PORCH ENAMEL - DARK GREEN.

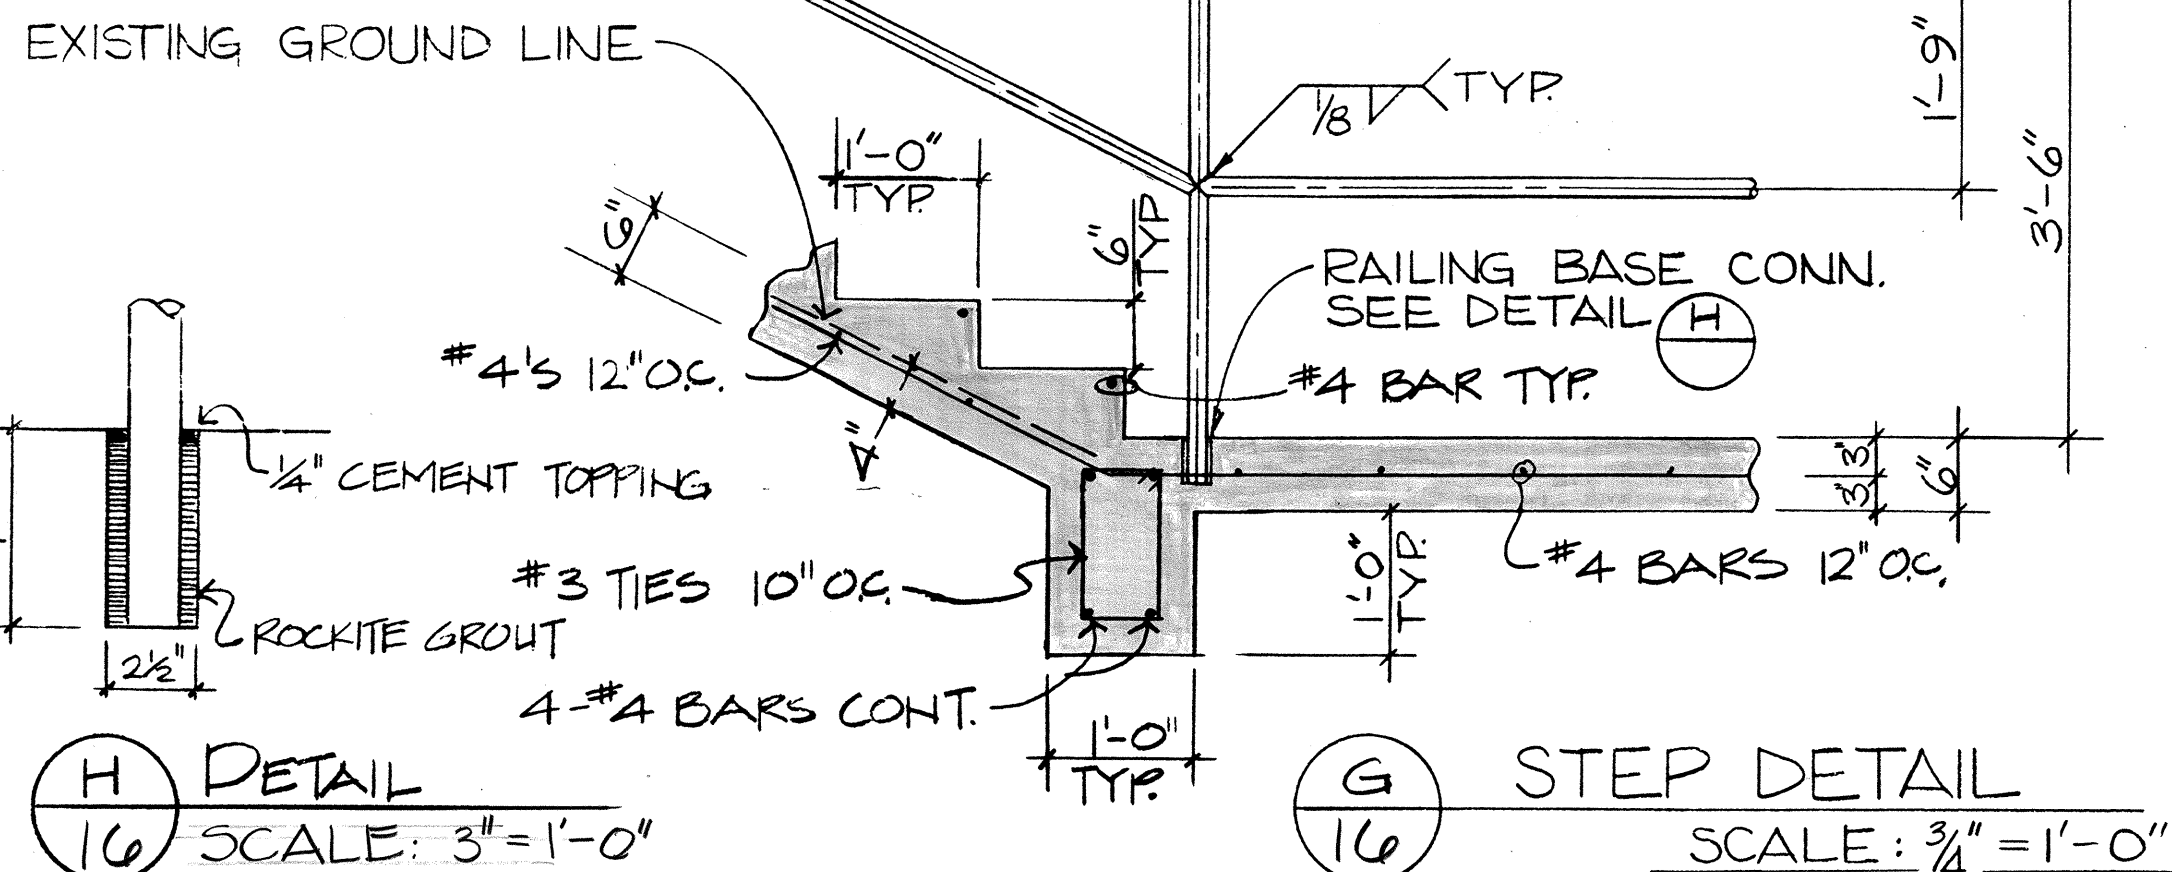

J DITCH DTL
SCALE: 1/2" = 1'-0"

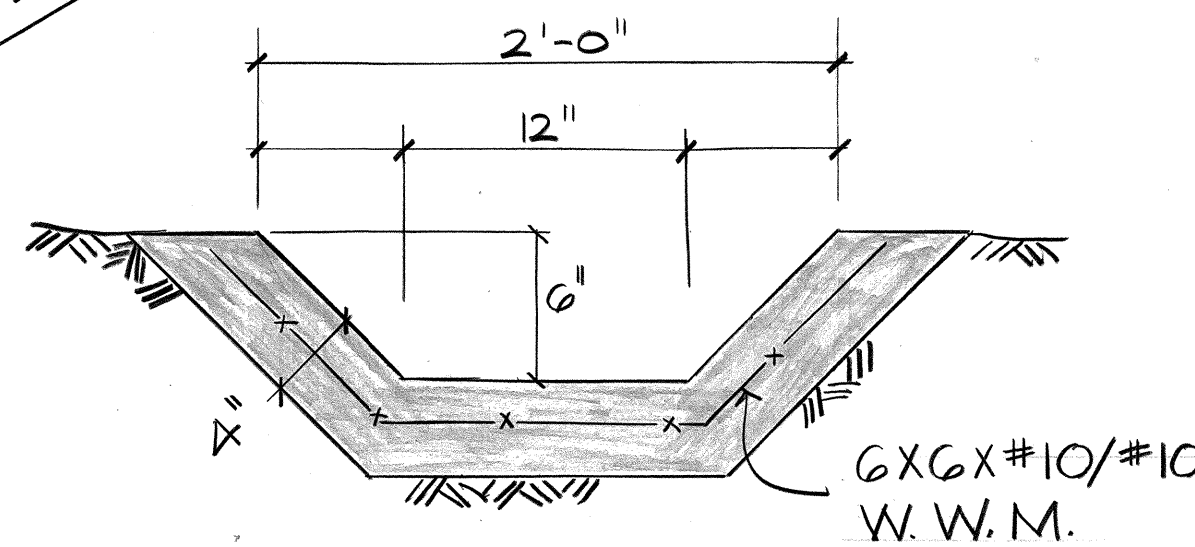



E PLAN - PUMPHOUSE
SCALE: 1/8" = 1'-0"

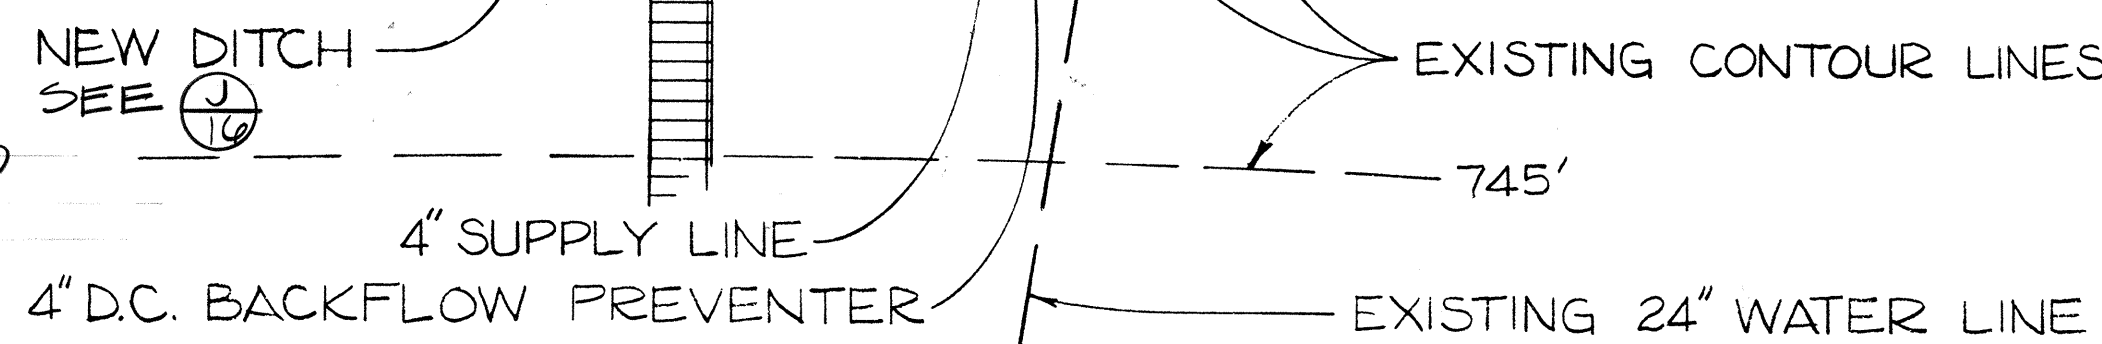

PIPE SUPPORT DIMENSIONS


	PUMP SUCTION PIPING	PUMP DISCHARGE PIPING
A	16"	16"
B	8"	8"
C	16"	56"
D	9"	50"

F DETAIL
N.T.S.

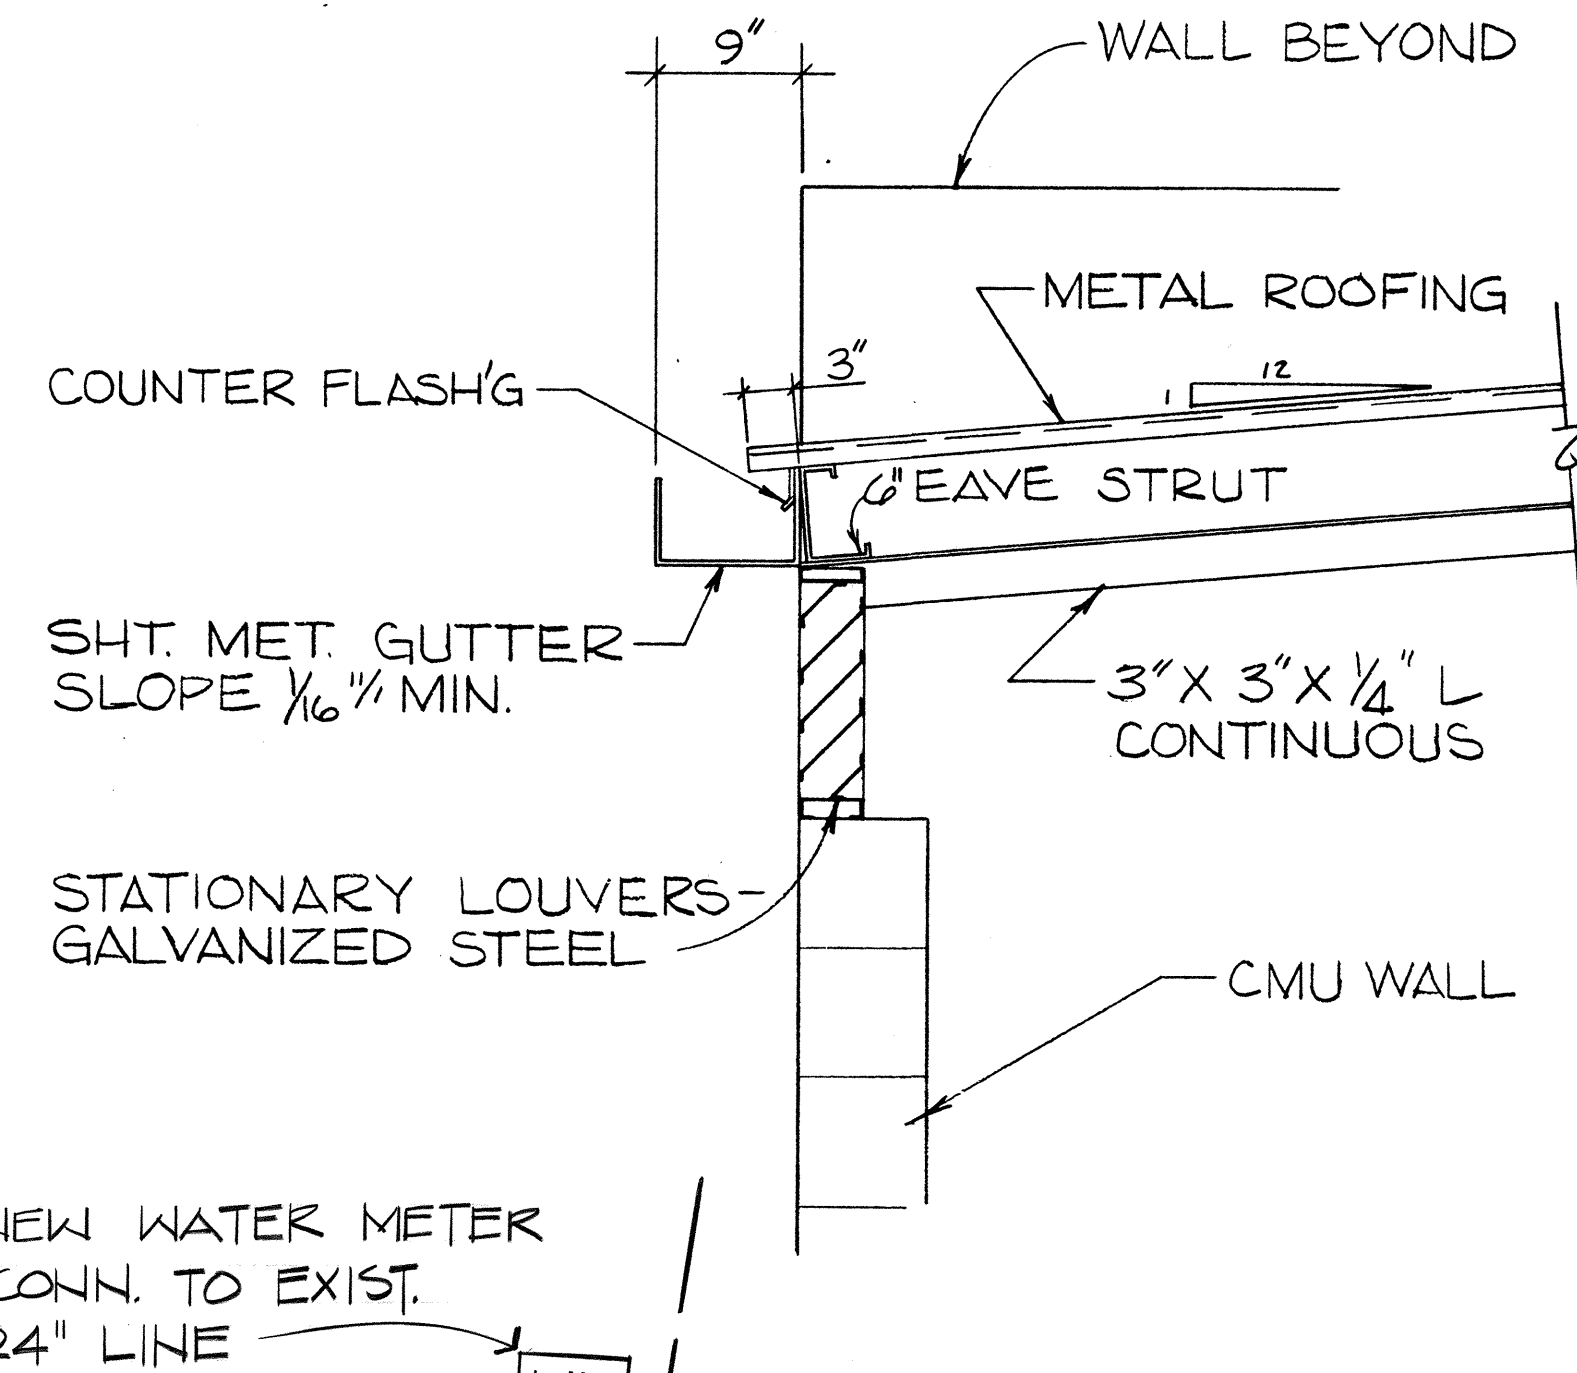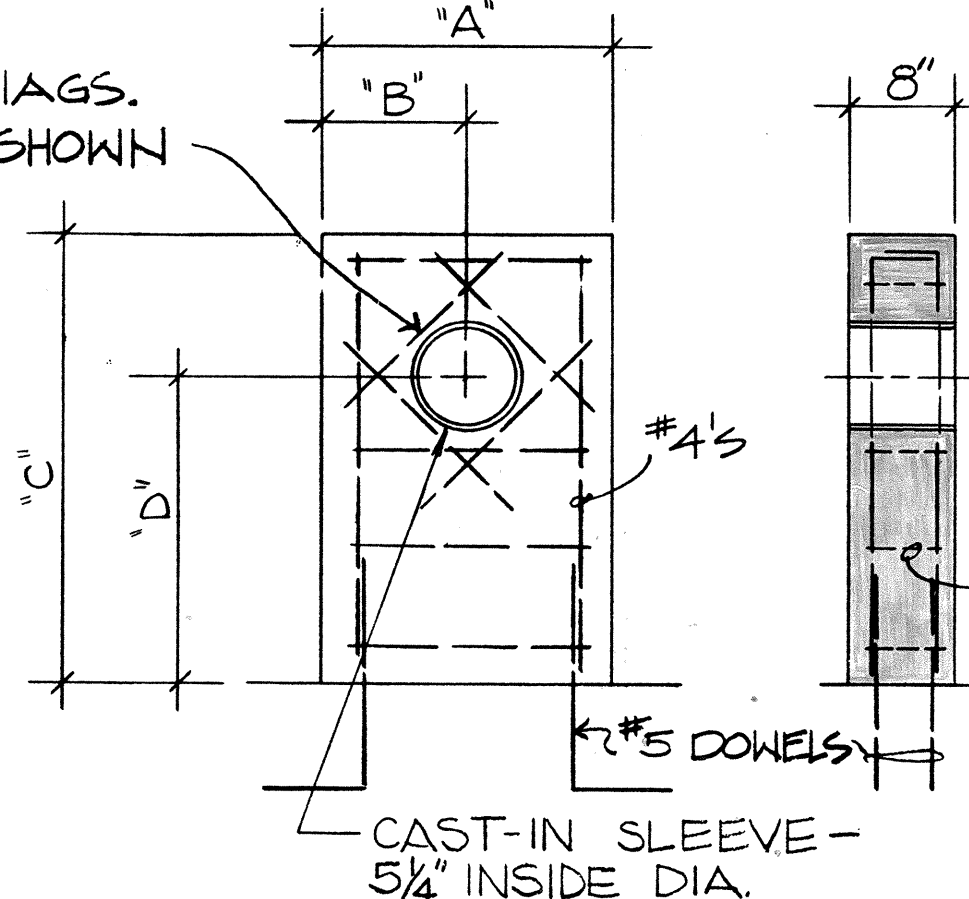


B SECTION
SCALE: 1" = 1'-0"



C FLASHING @ SIDE WALL DET.
SCALE: 1/2" = 1'-0"

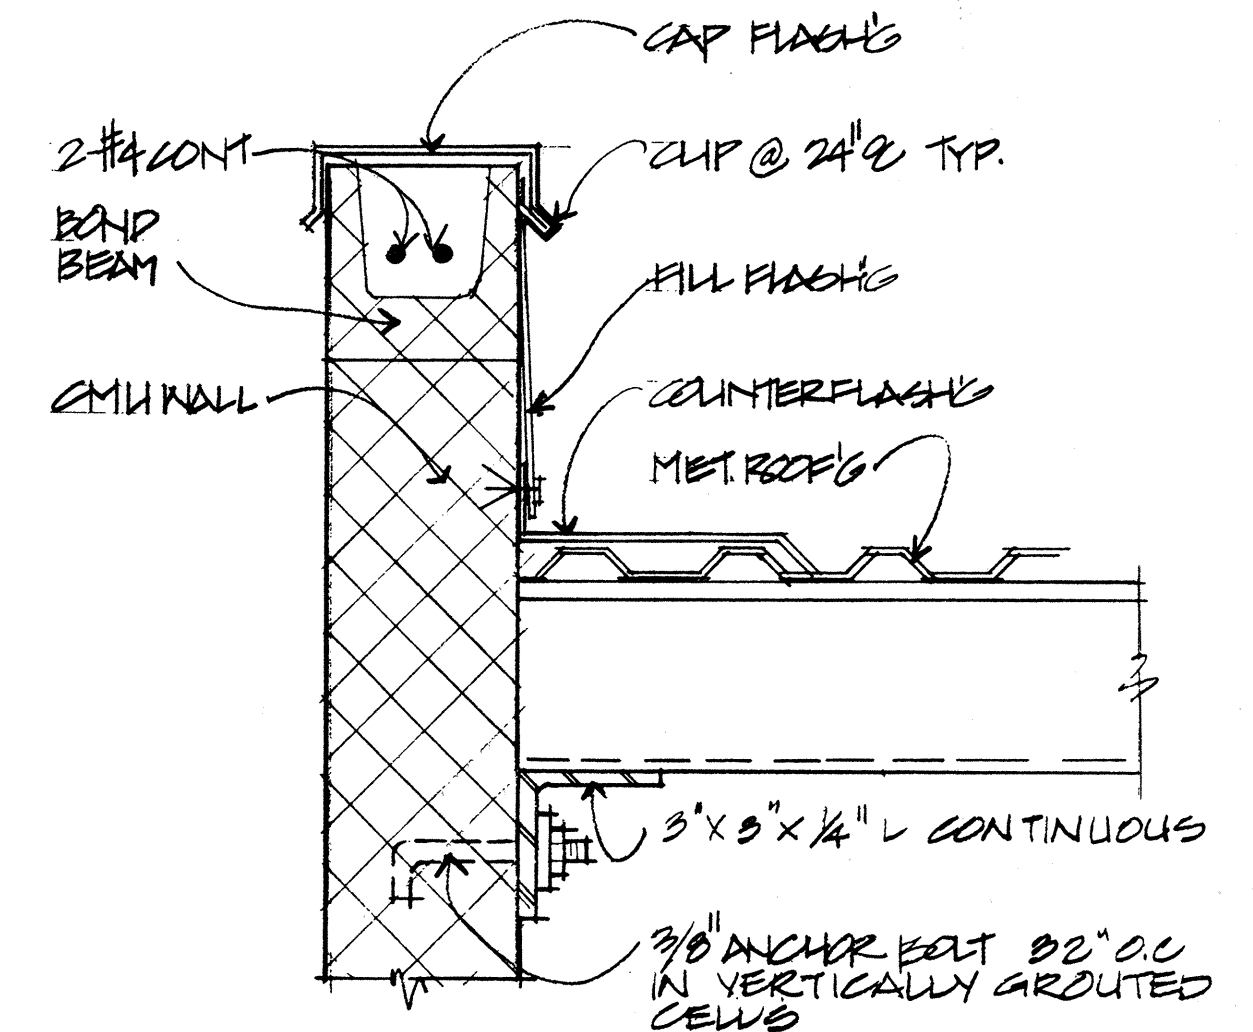

D FLASHING @ BACK WALL
SCALE: 1/2" = 1'-0"








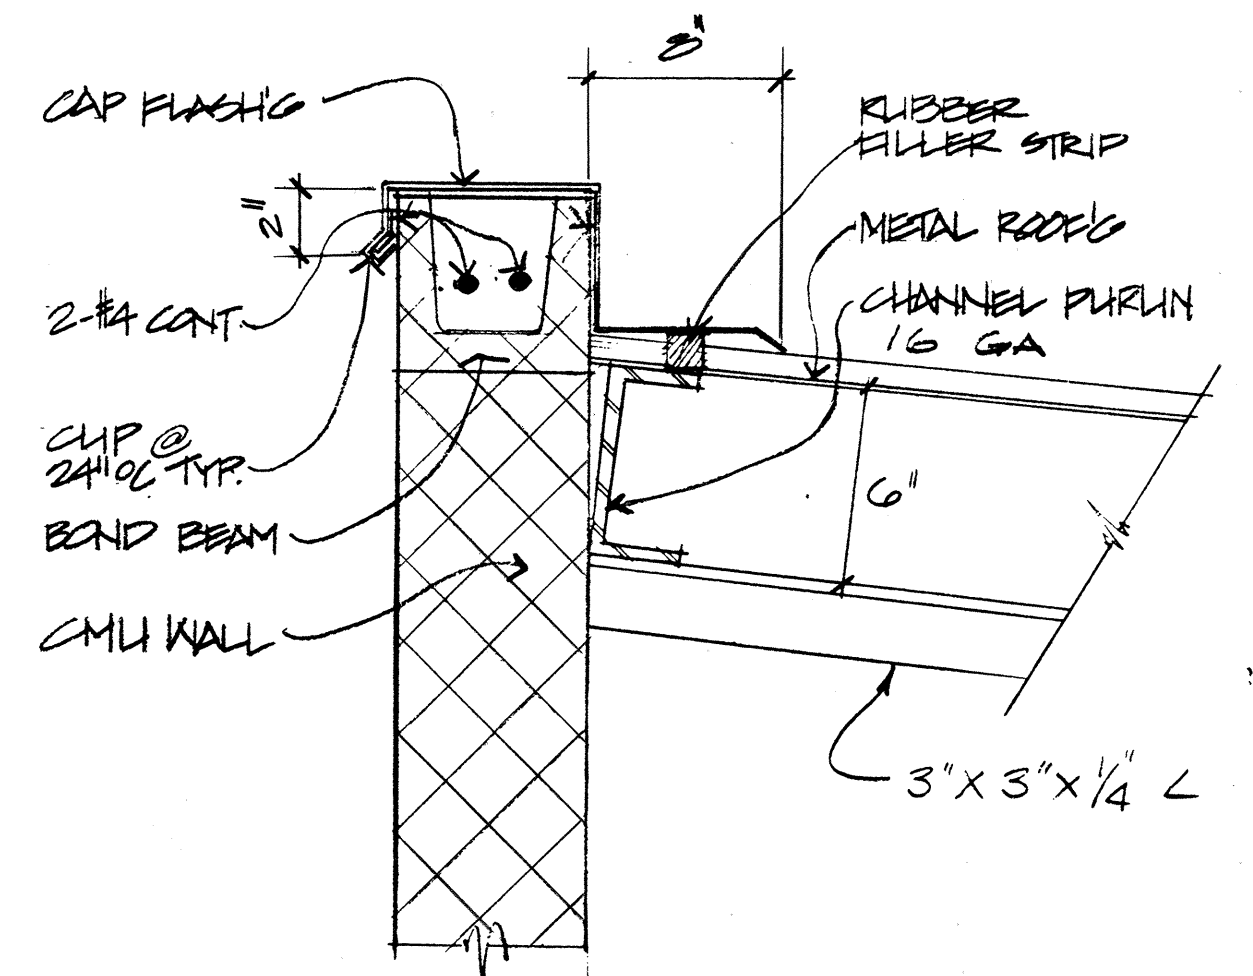


DATE	
SURVEY PLOTTED BY	
DRAWN BY	
CHECKED BY	
NOTES BOOK	
QUANTITIES BY	
CHECKED BY	

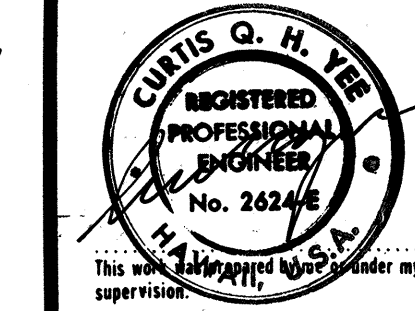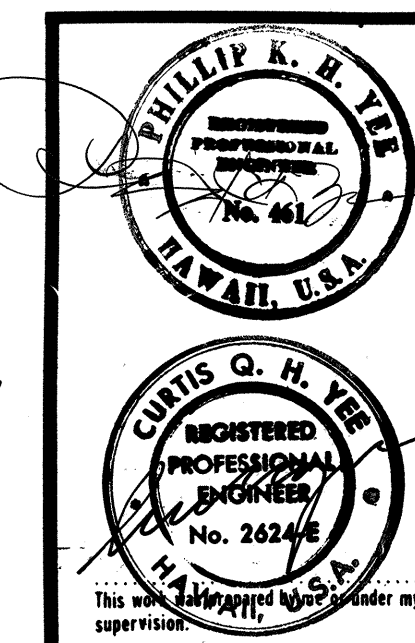

STATE OF HAWAII
DEPARTMENT OF TRANSPORTATION
HIGHWAYS DIVISION
PROJECT NO. I-H2-1(13):4
MILILANI INTERCHANGE
PUMP HOUSE
DETAILS
SHEET No. 16 OF 25 SHEETS

FED. ROAD DIST. NO.	STATE	FED. AID PROJ. NO.	FISCAL YEAR	SHEET NO.	TOTAL SHEETS
HAWAII	HAW.	I-H2-1(13)-4	1977	26	34

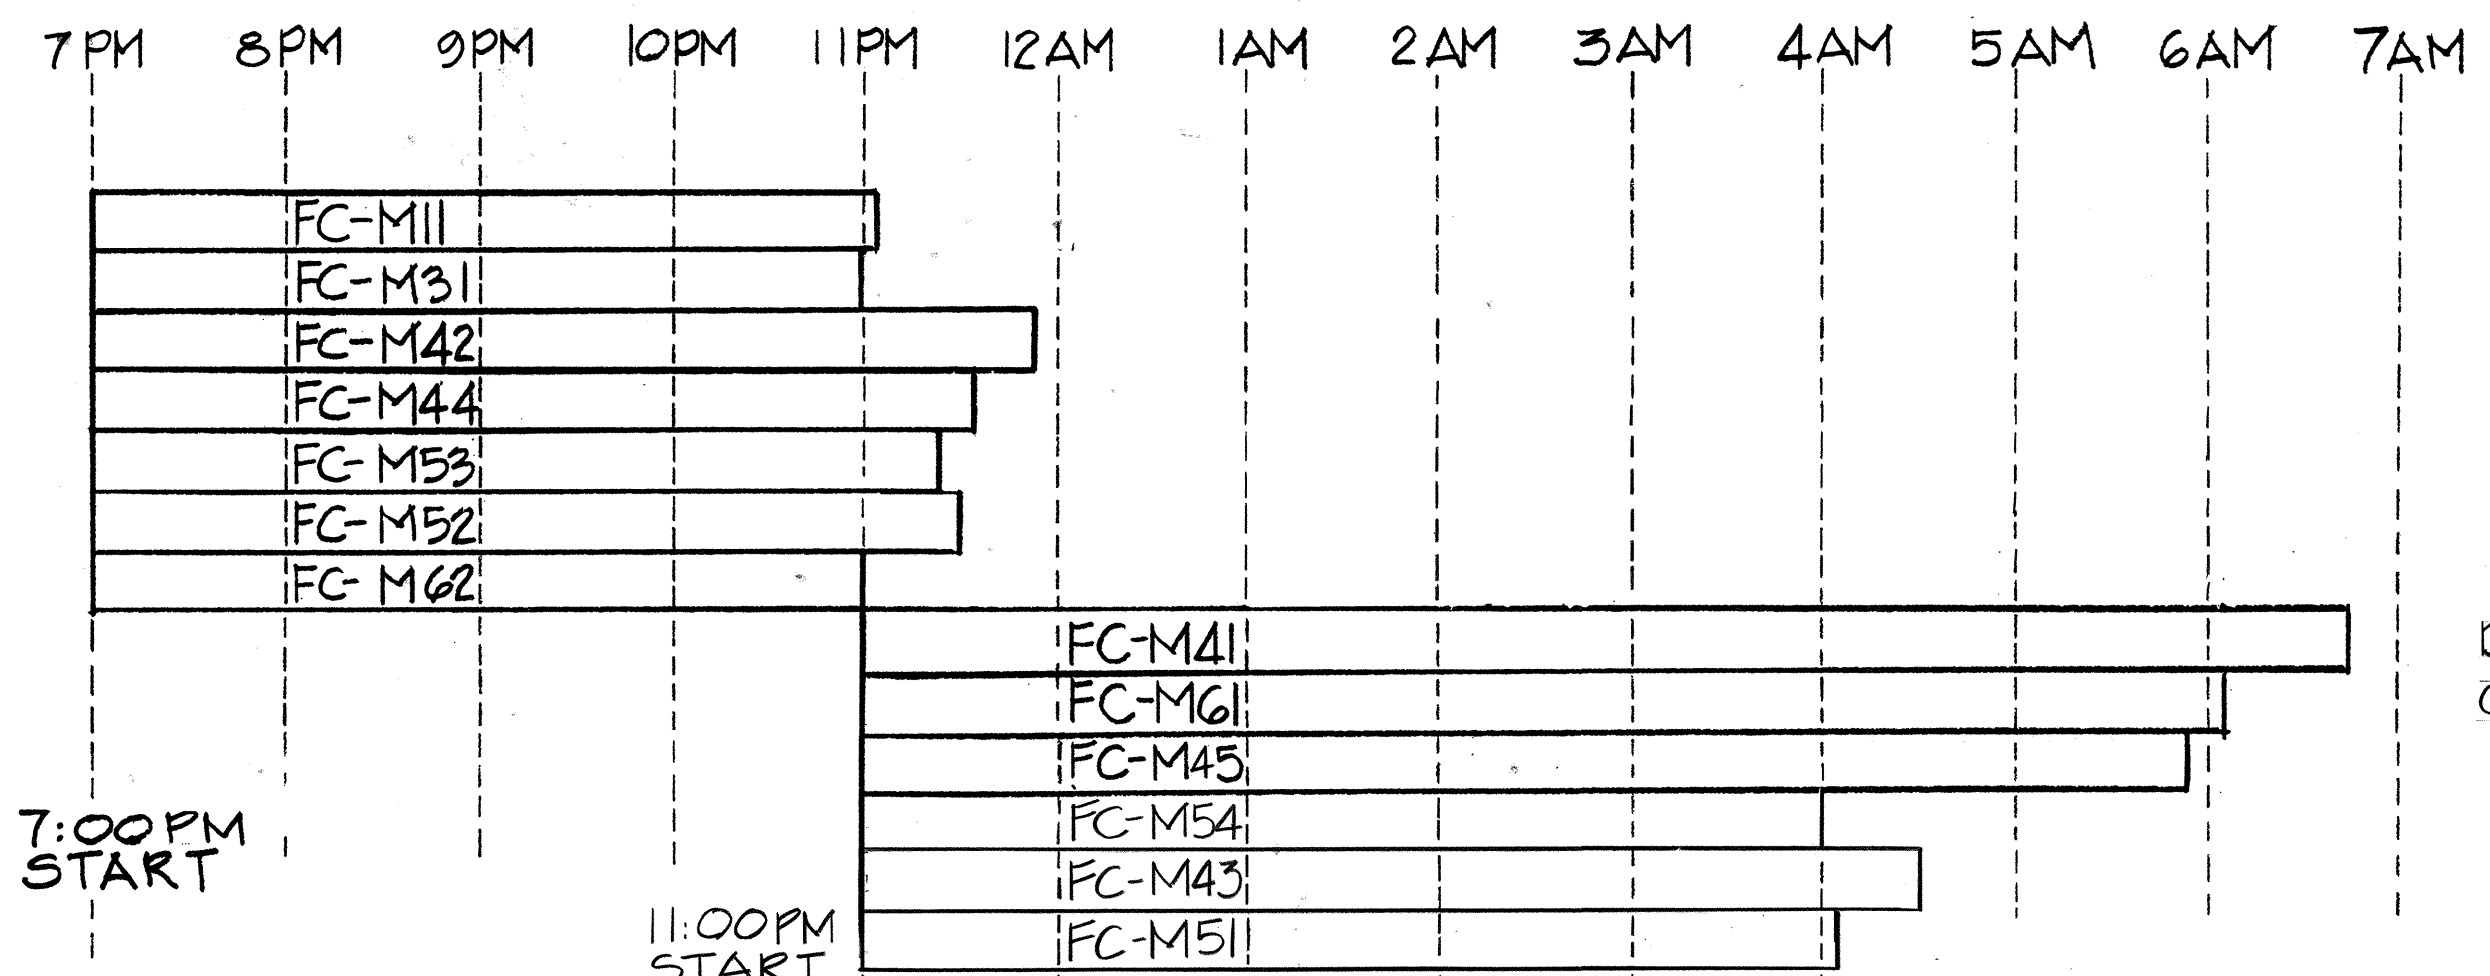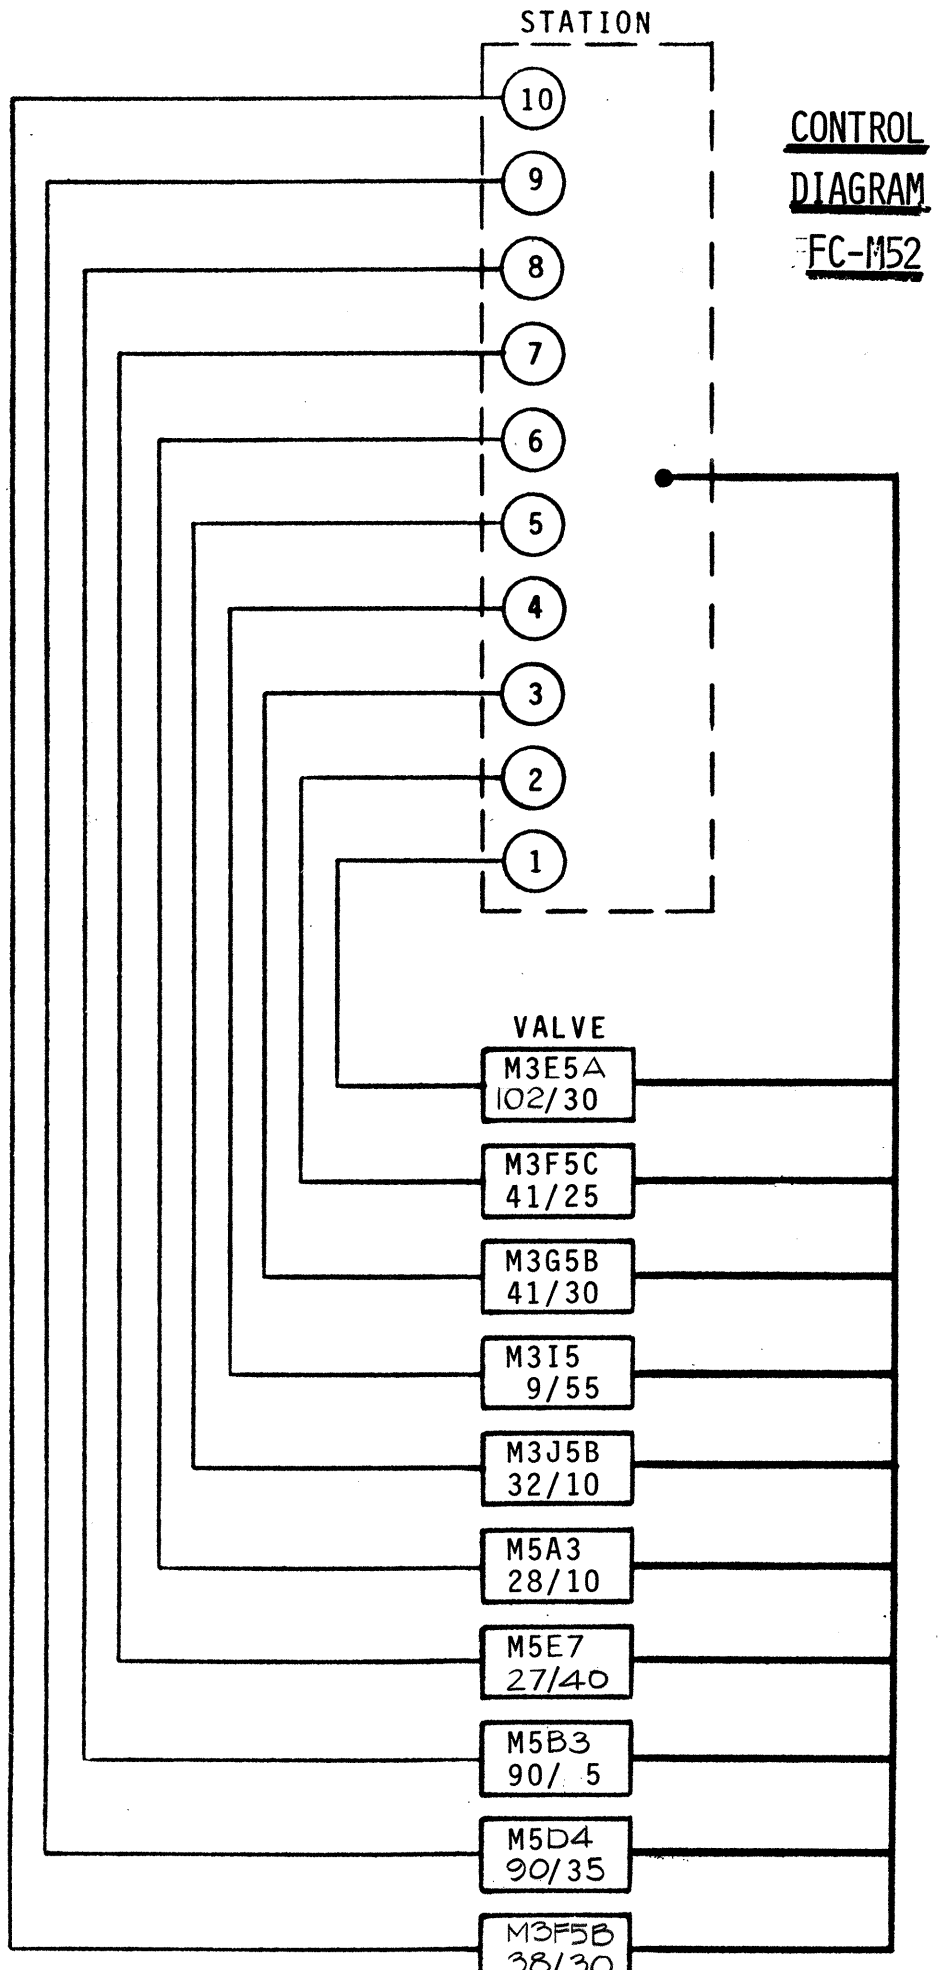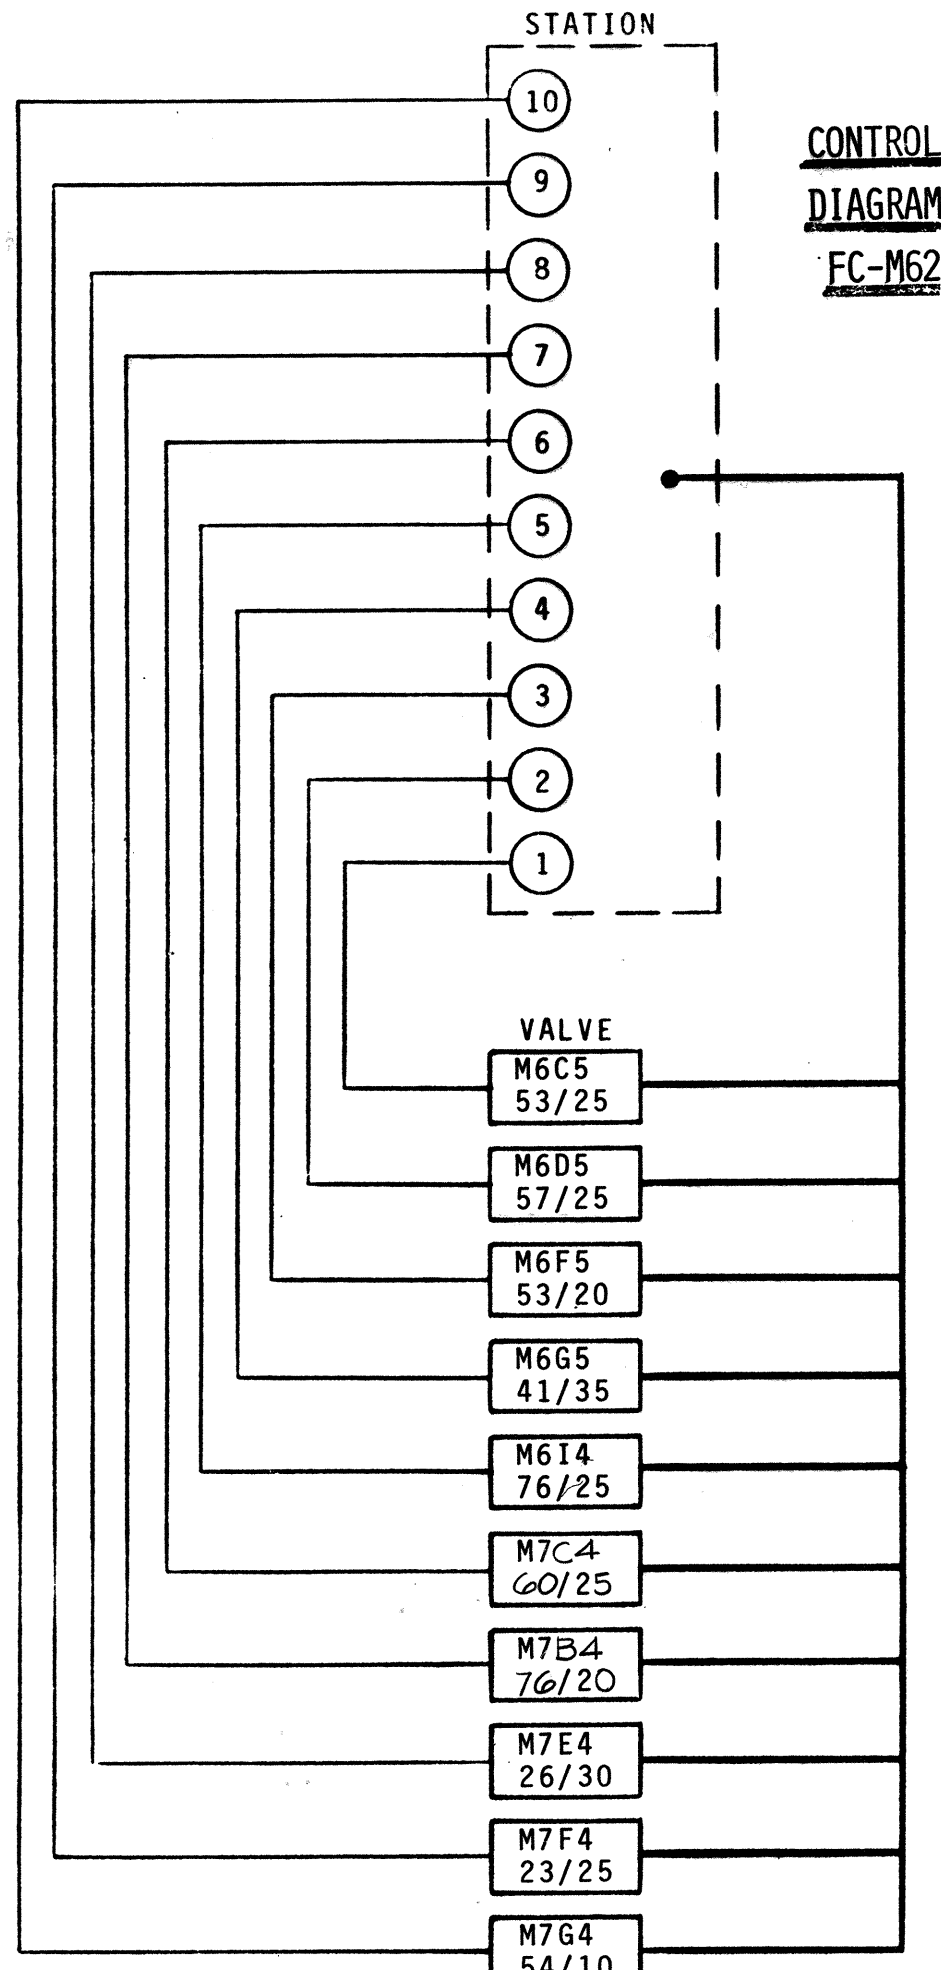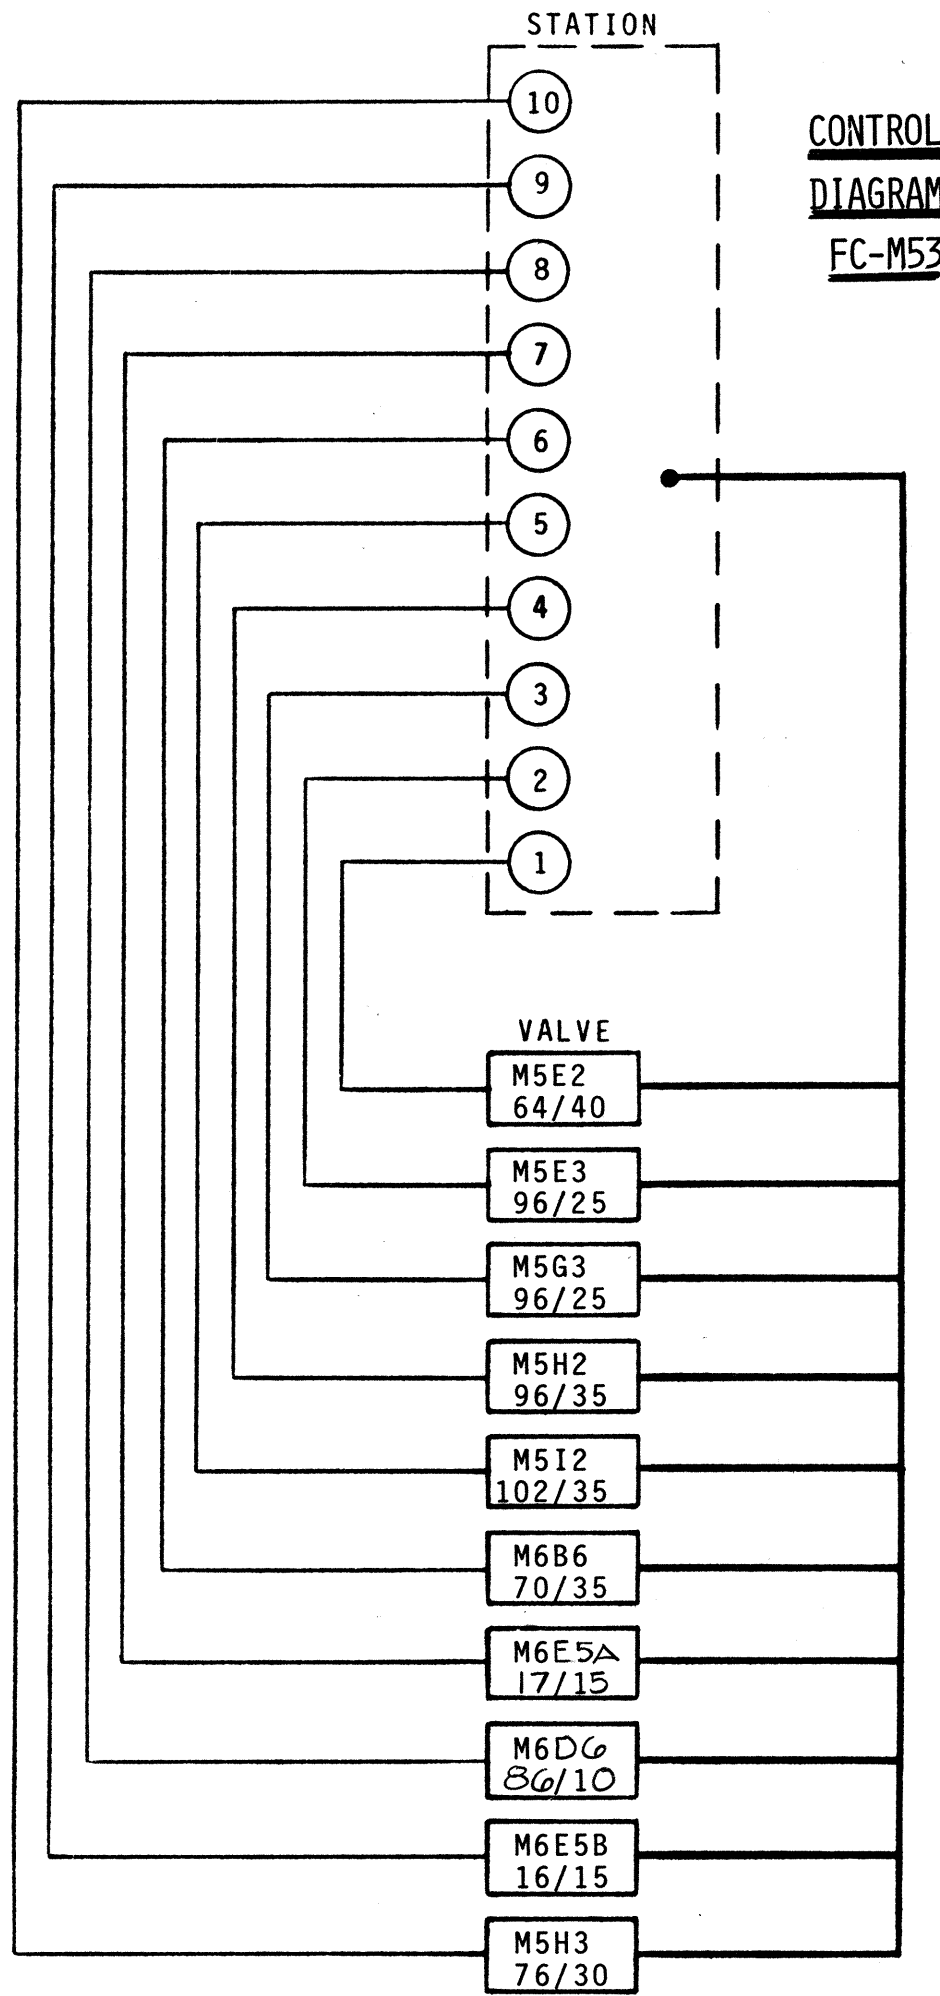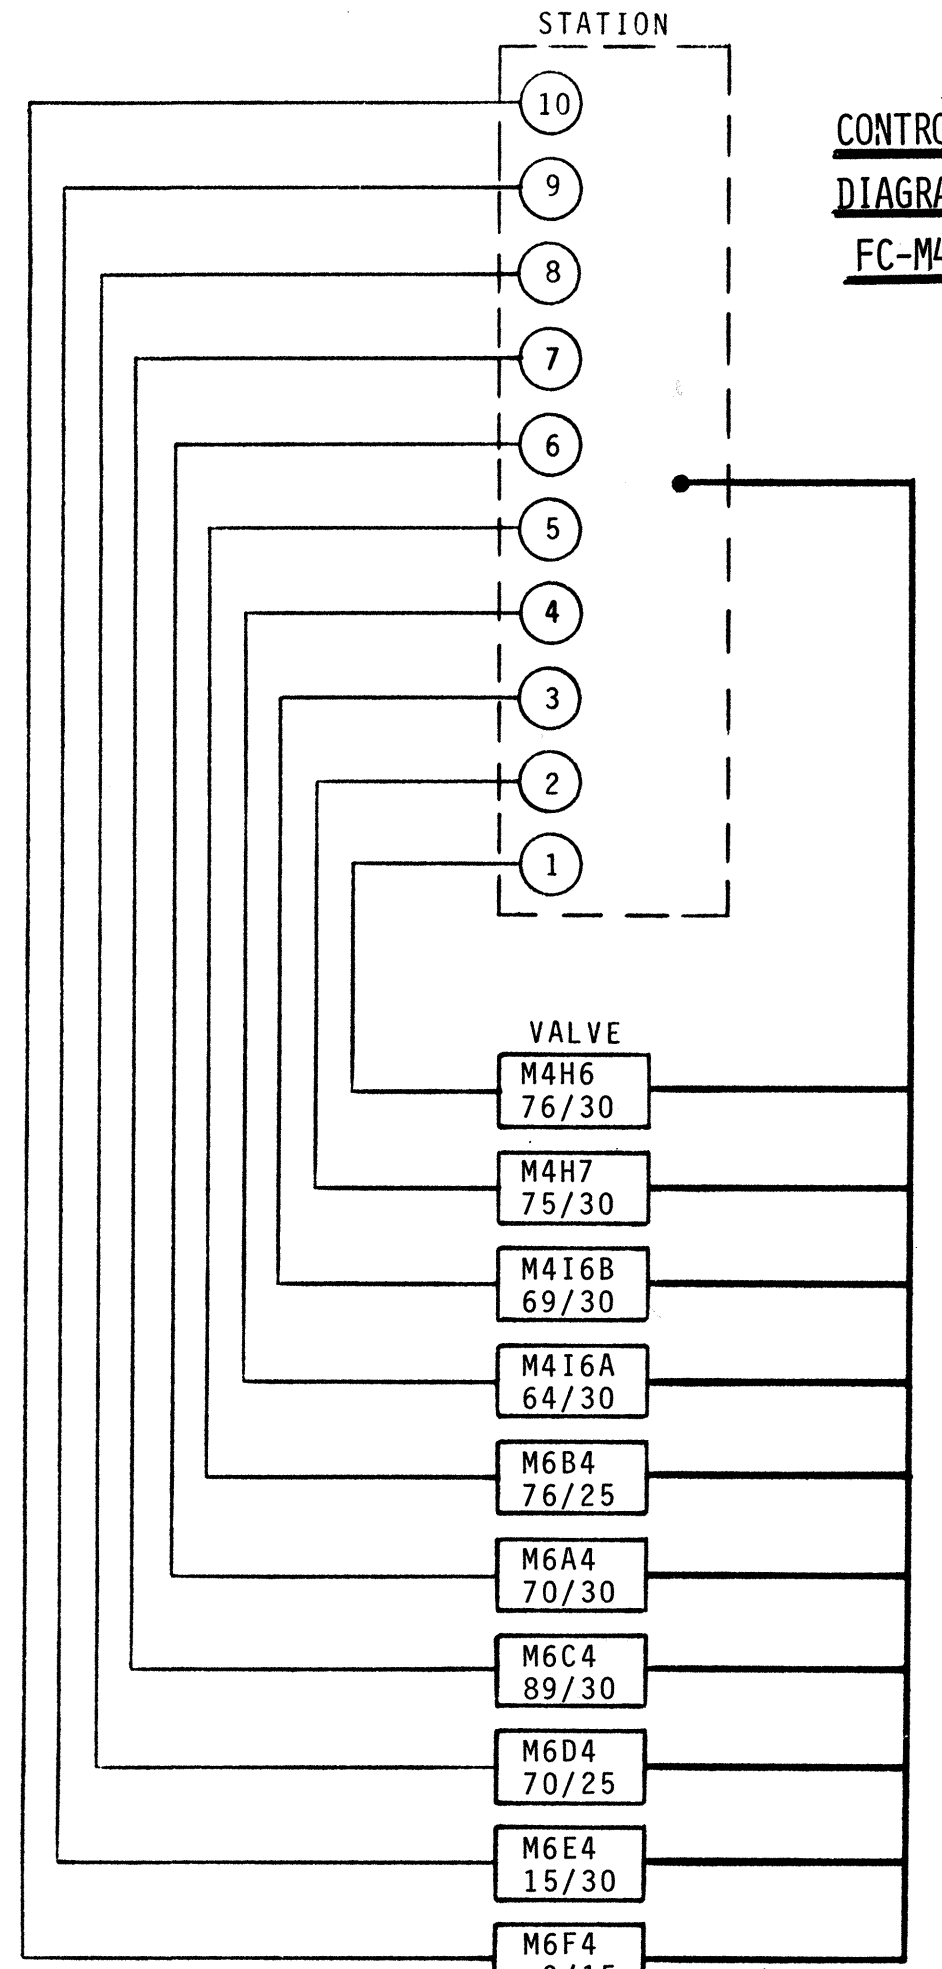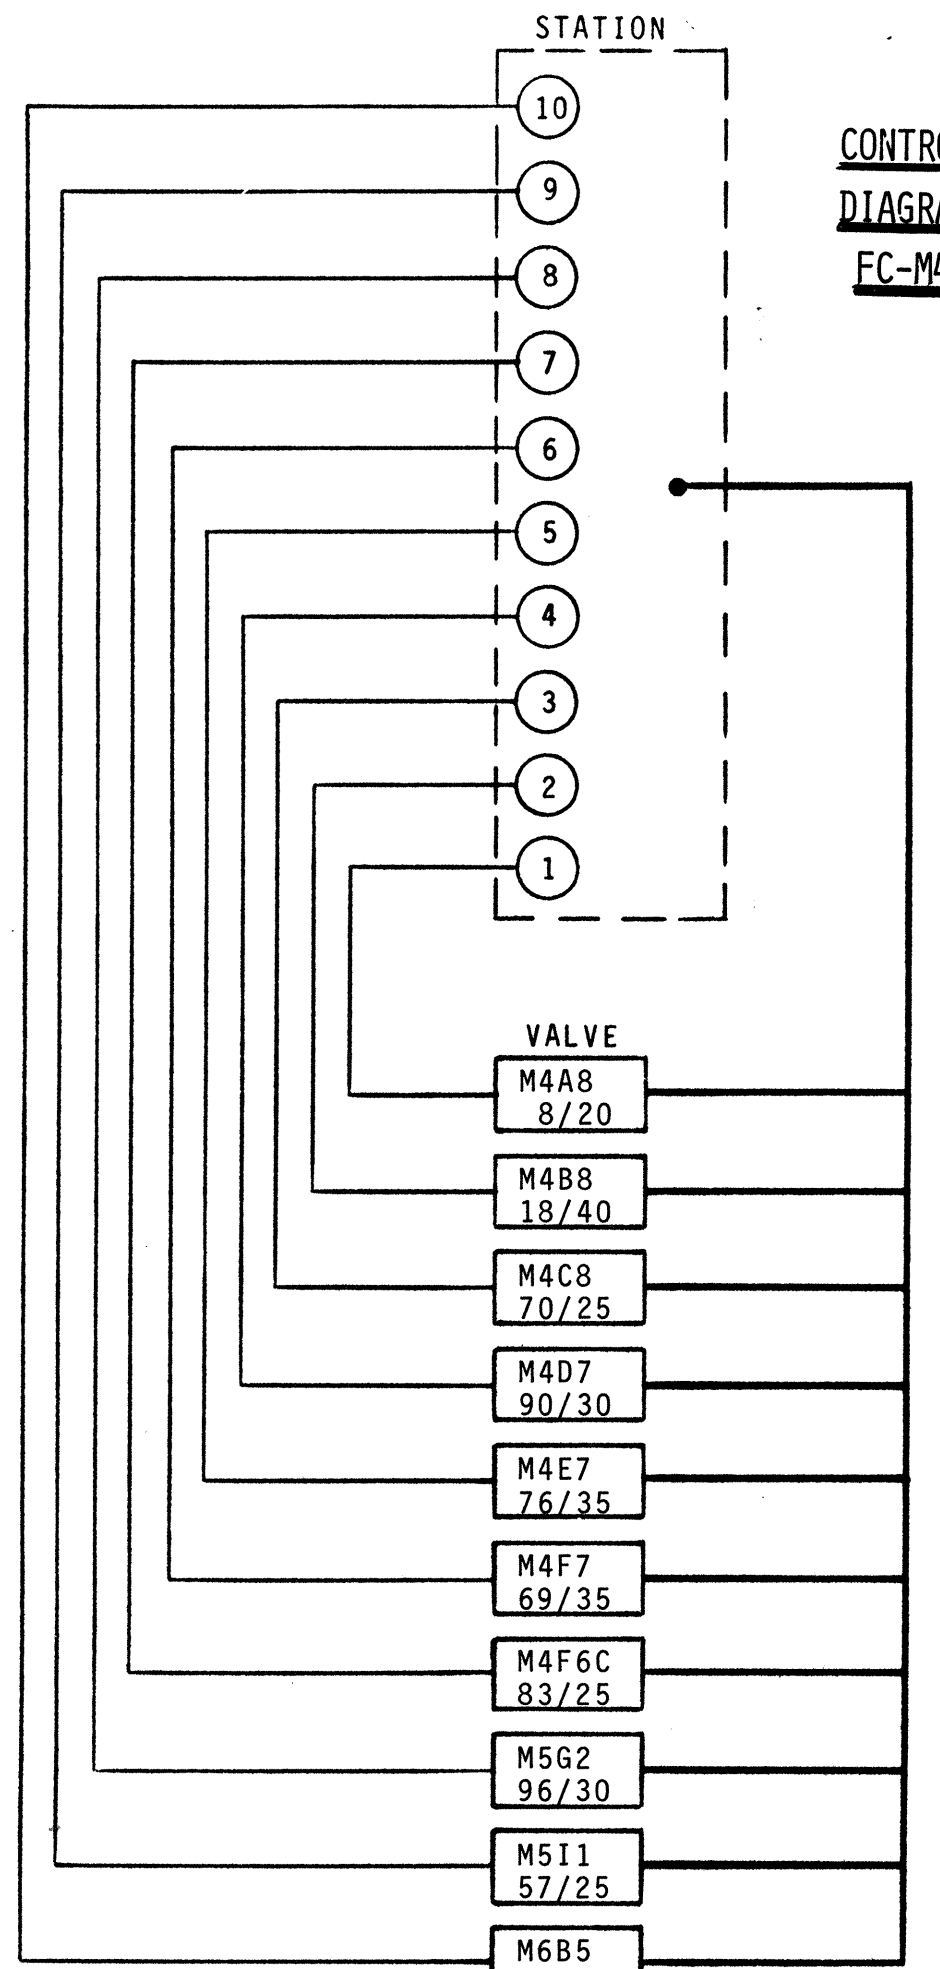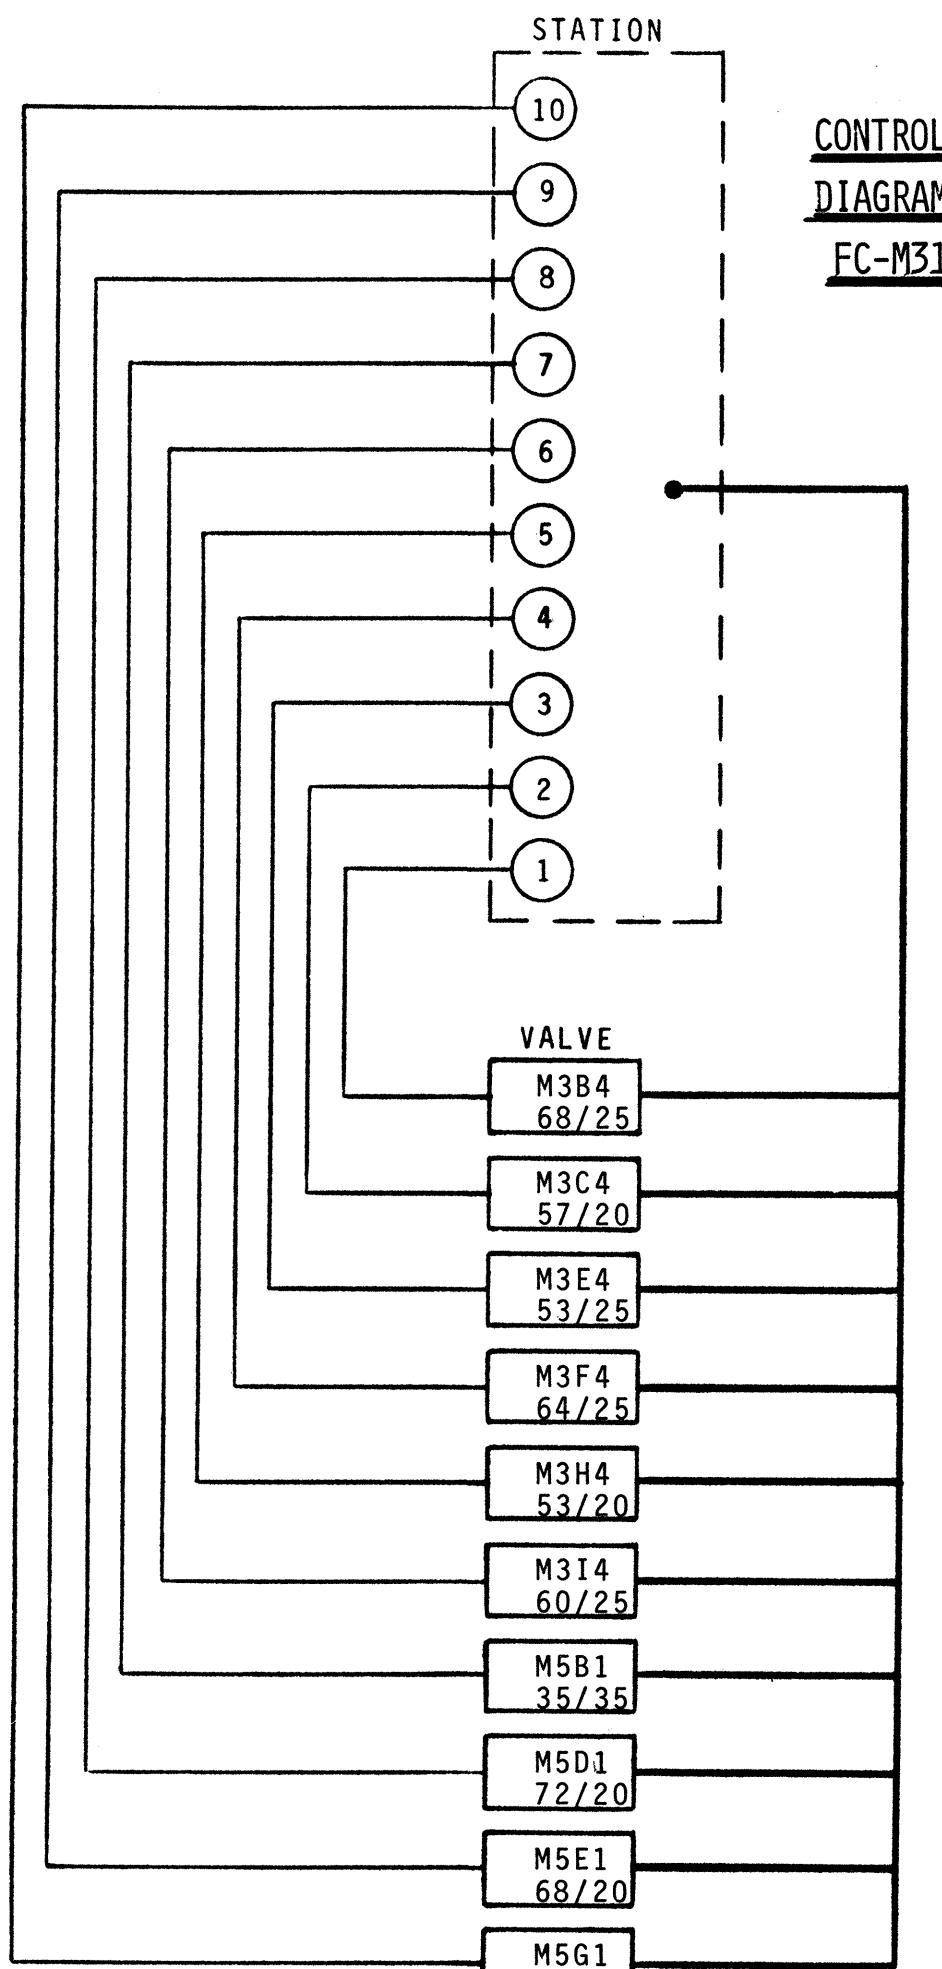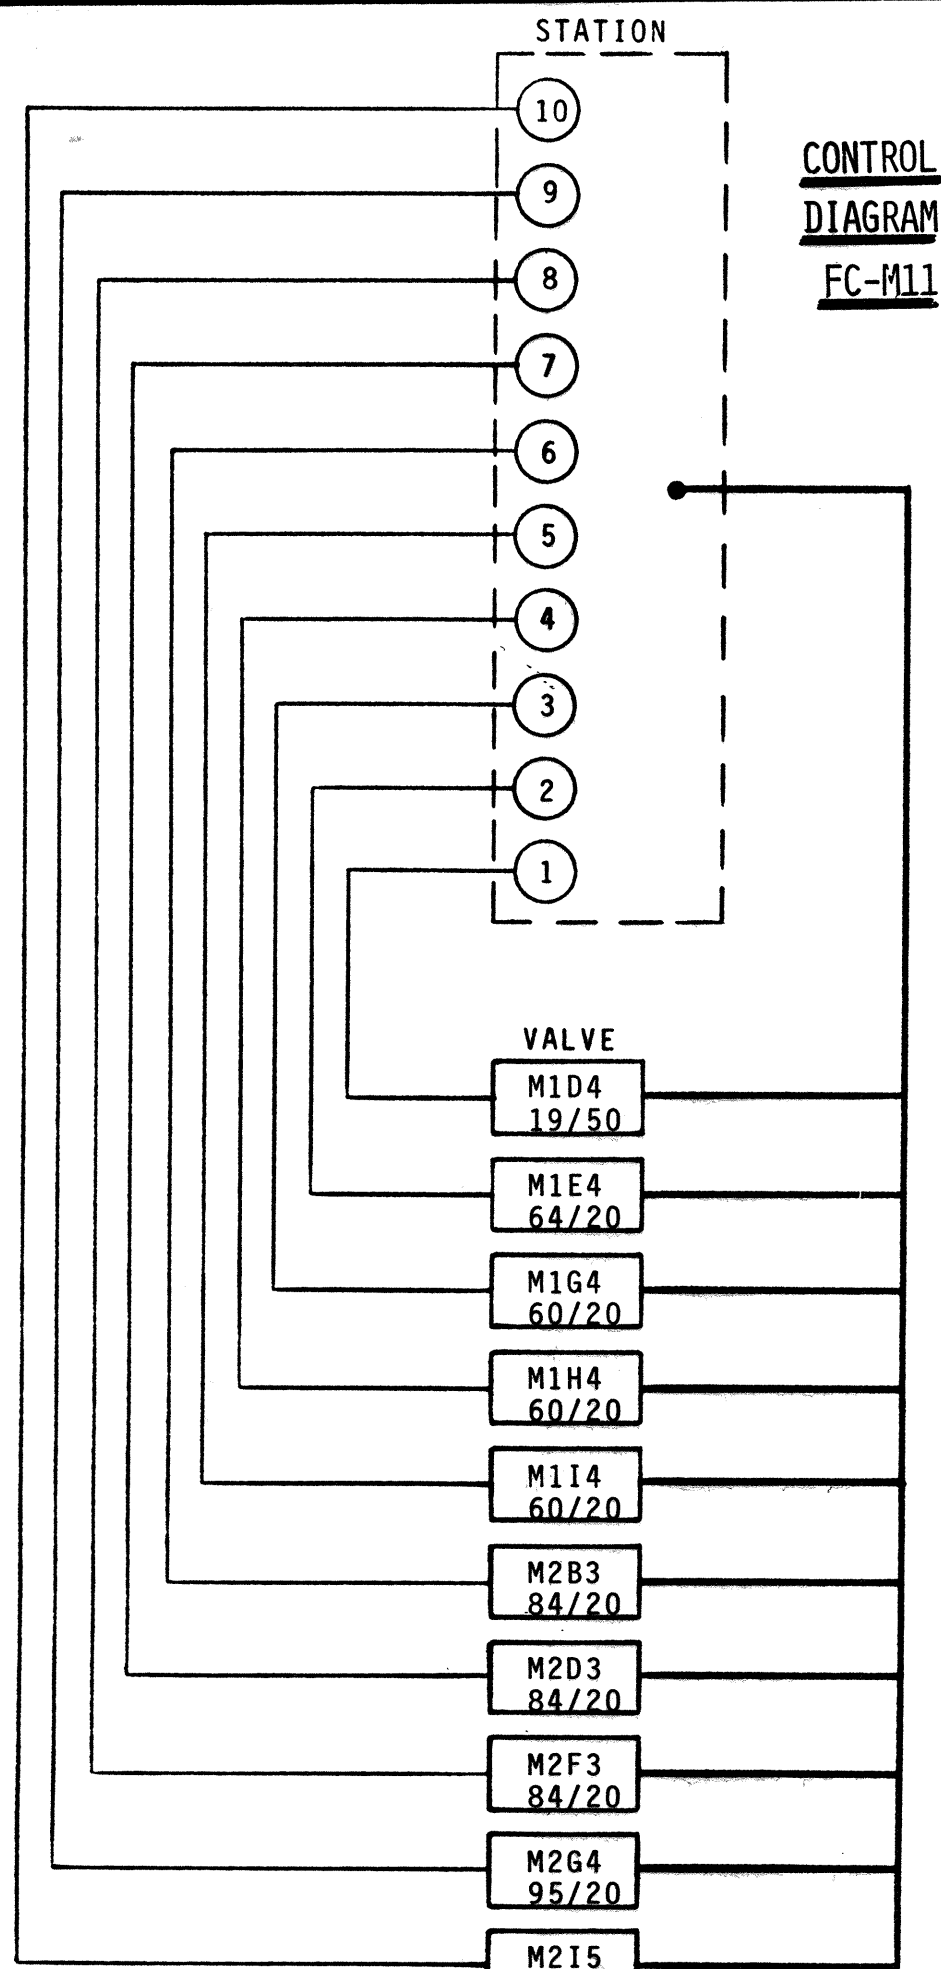

SPRINKLER BANK WHERE VALVE IS LOCATED

DISCHARGE OF BANK (GPM)

DURATION (MIN)

EXPLANATION OF VALVE IDENTIFICATION

DATE	_____
DESIGNED BY	_____
CHECKED BY	_____
NOTED BY	_____
NO.	_____



STATE OF HAWAII
DEPARTMENT OF TRANSPORTATION
HIGHWAYS DIVISION








PROJECT NO. I-H2-1(13)-4

MILILANI INTERCHANGE

CONTROL DIAGRAMS

SHEET No. 17 OF 25 SHEETS

FED. ROAD DIST. NO.	STATE	FED. AID PROJ. NO.	FISCAL YEAR	SHEET NO.	TOTAL SHEETS
HAWAII	HAW.	I-H2-1(13):4	1977	27	34

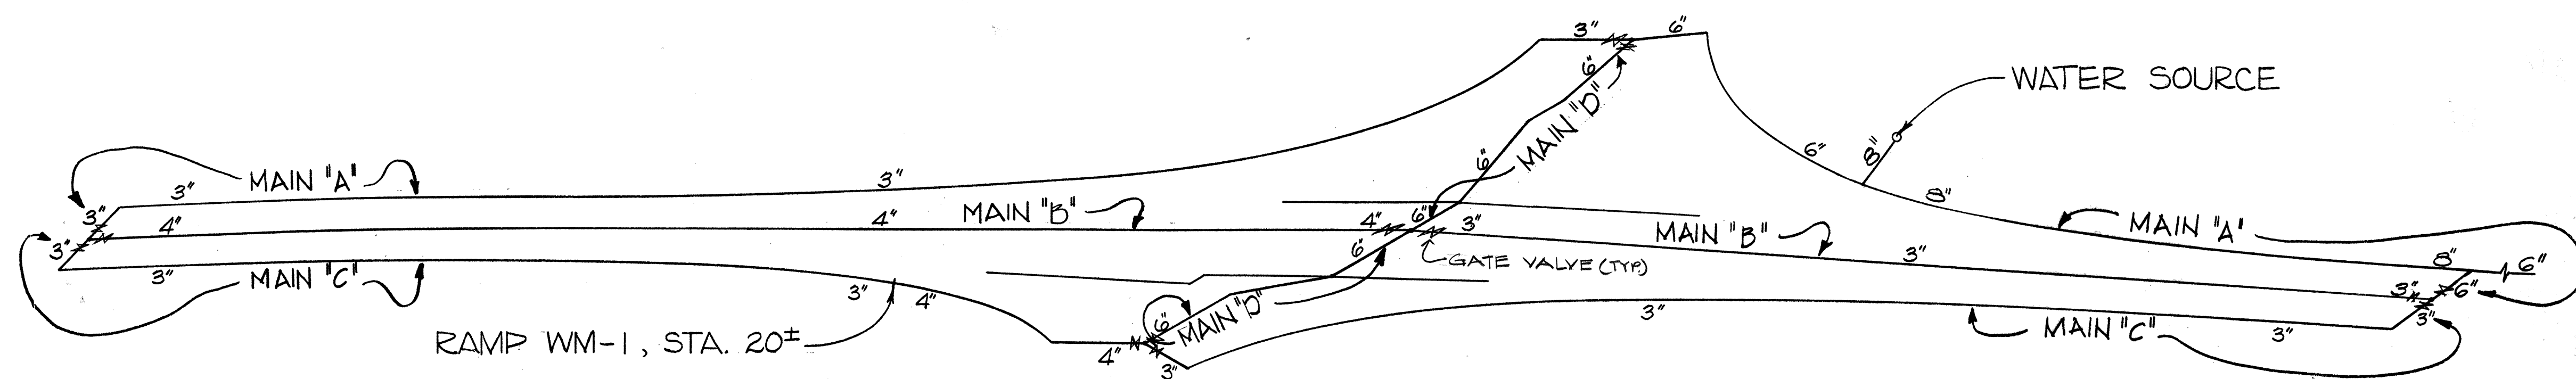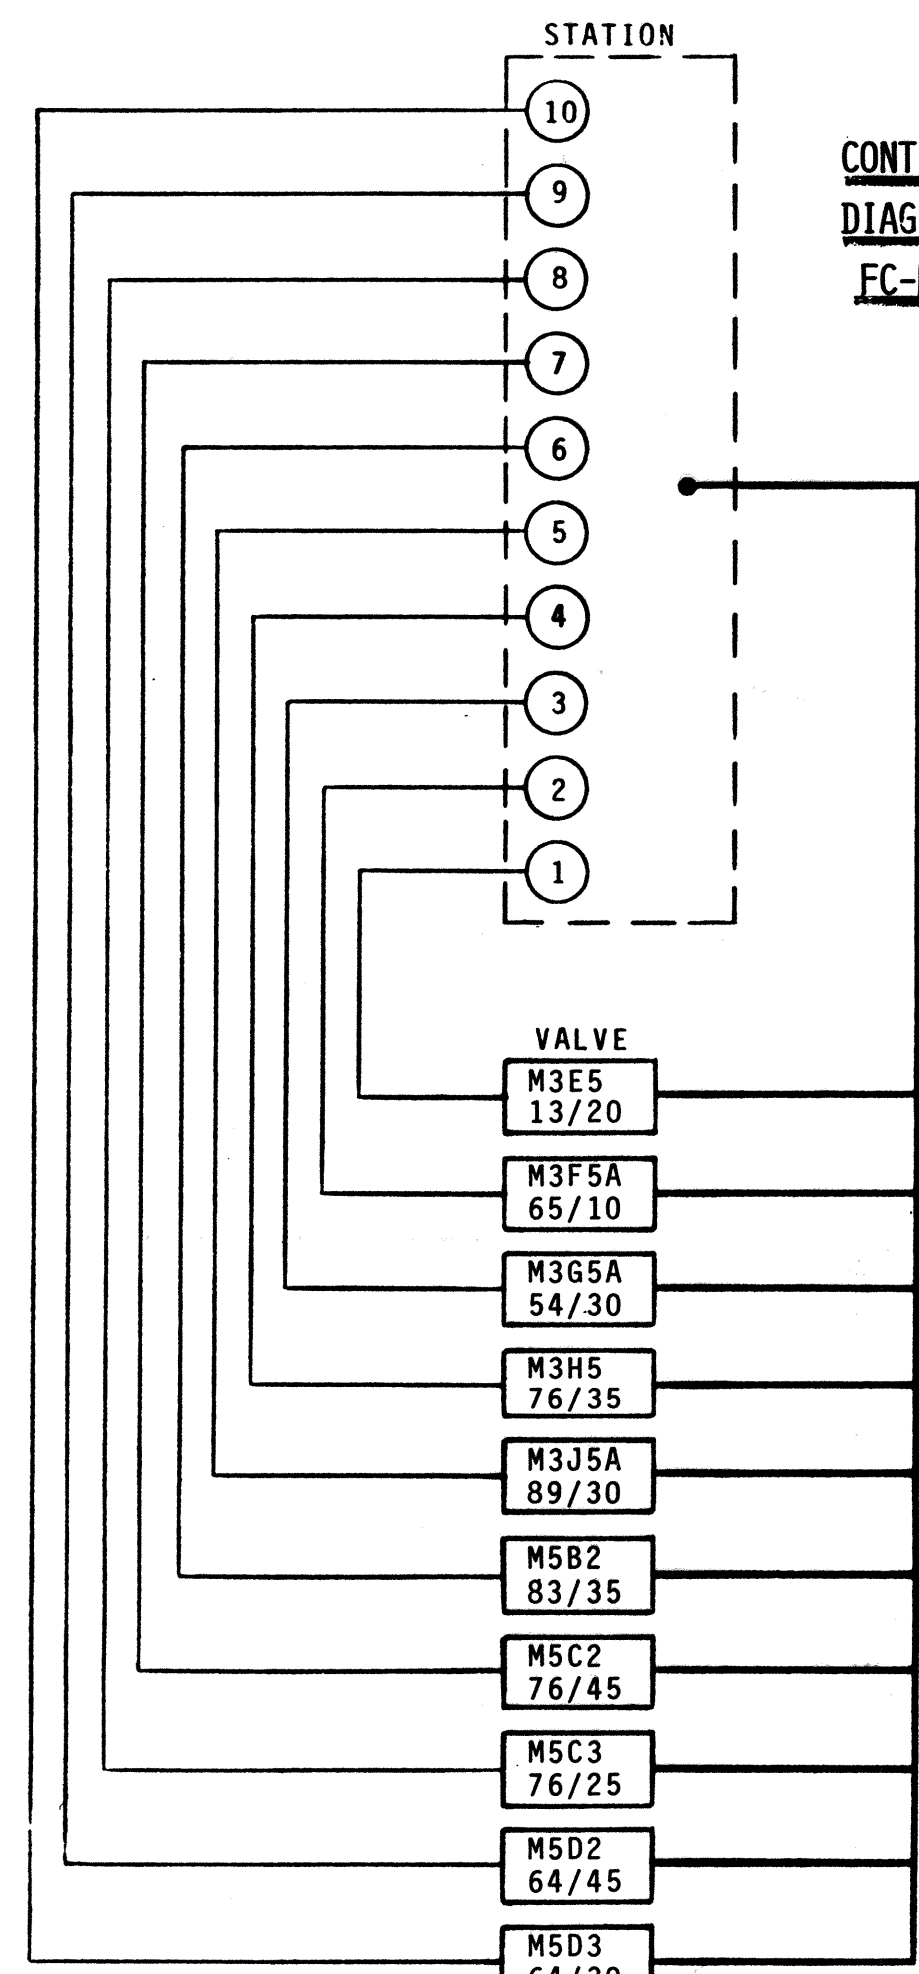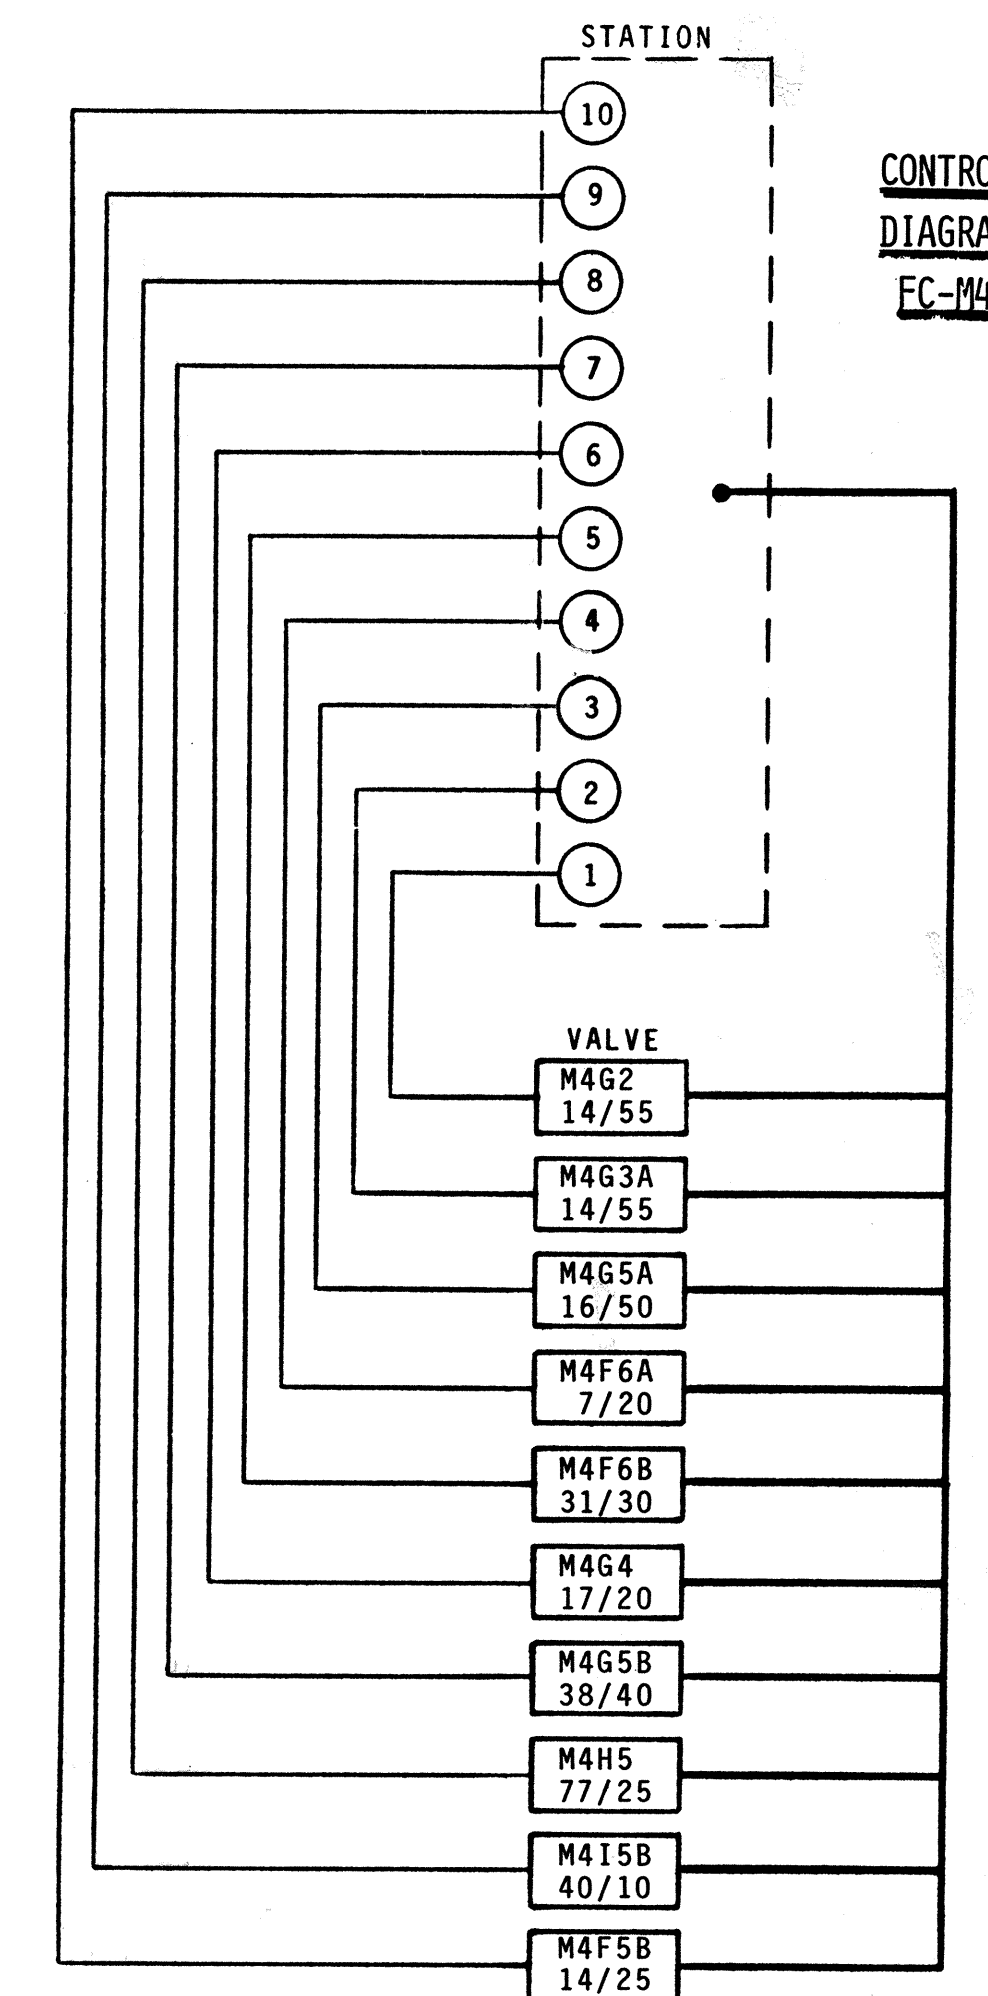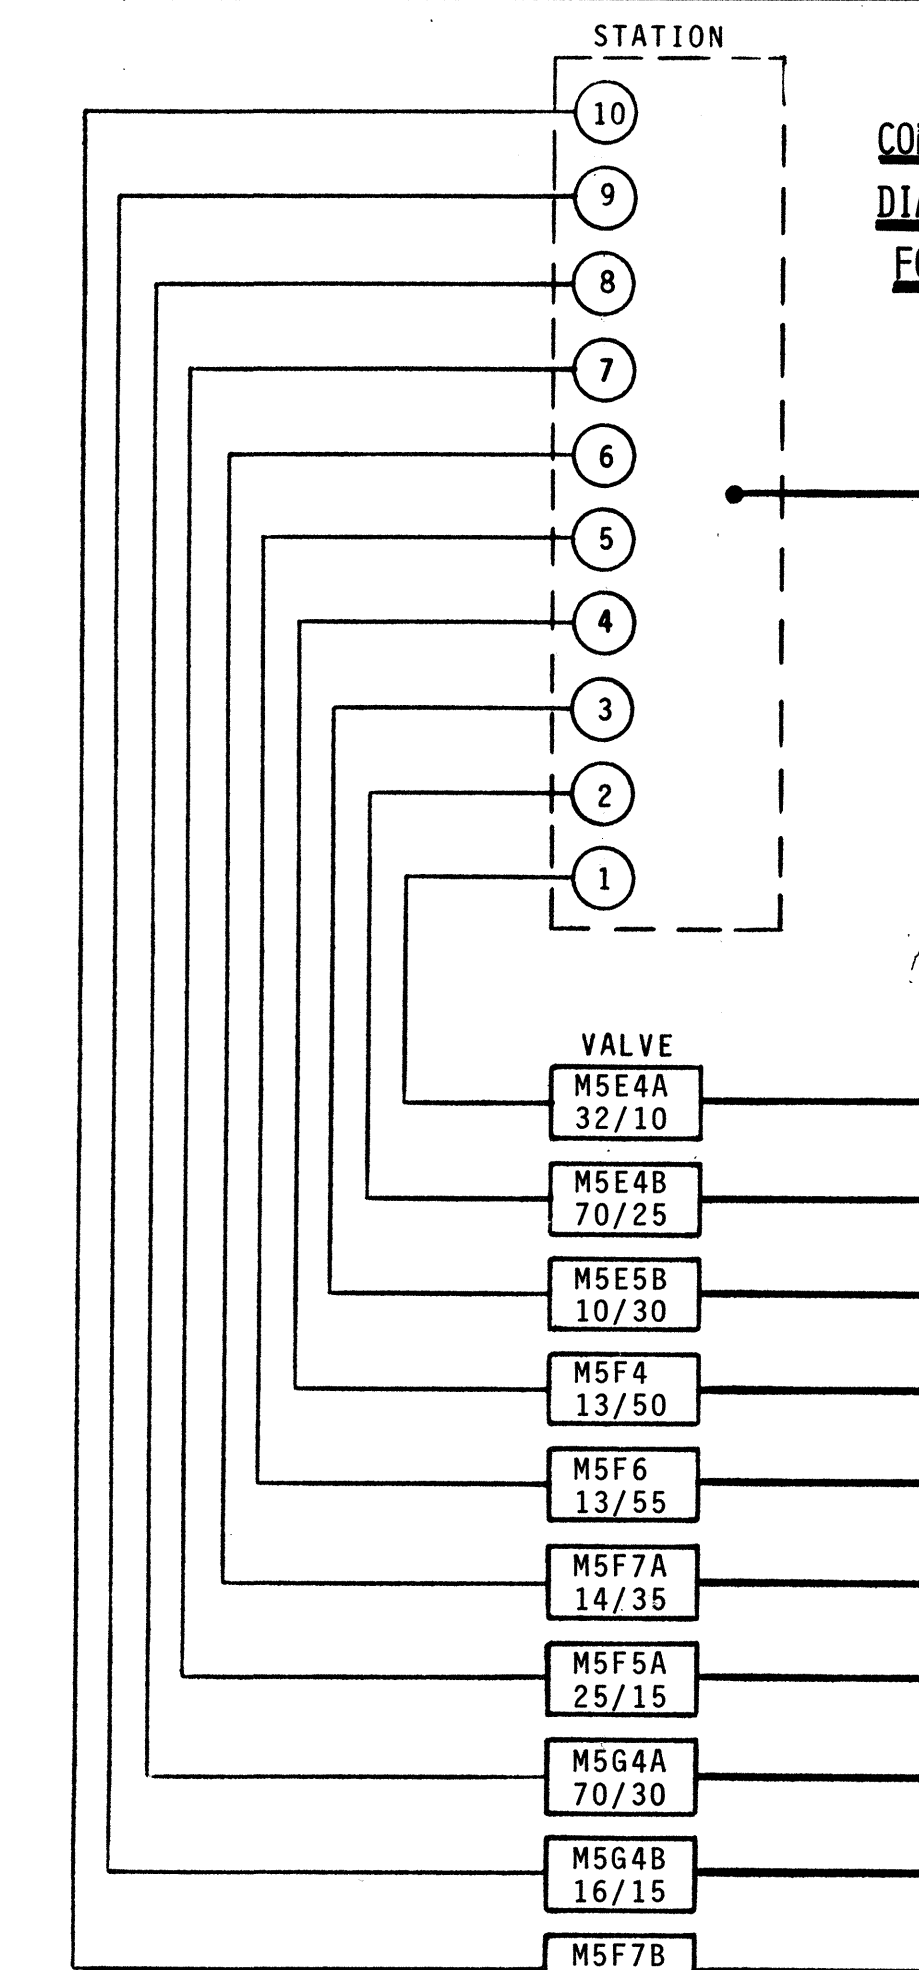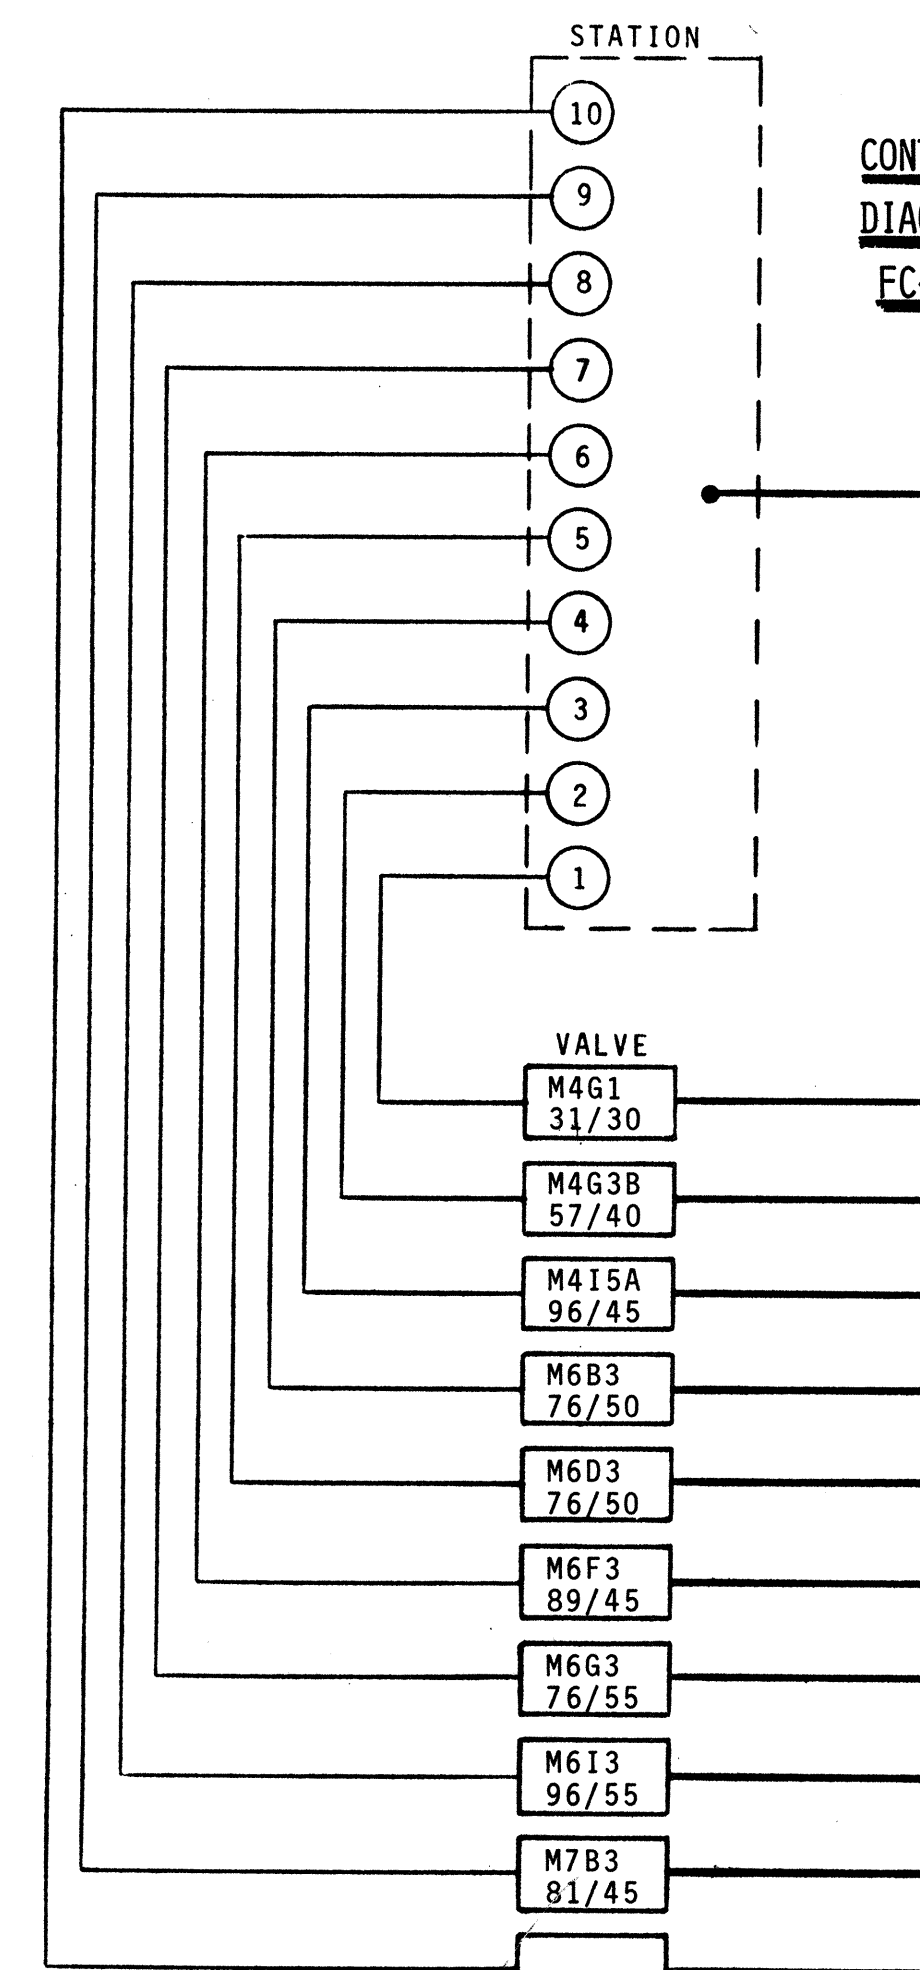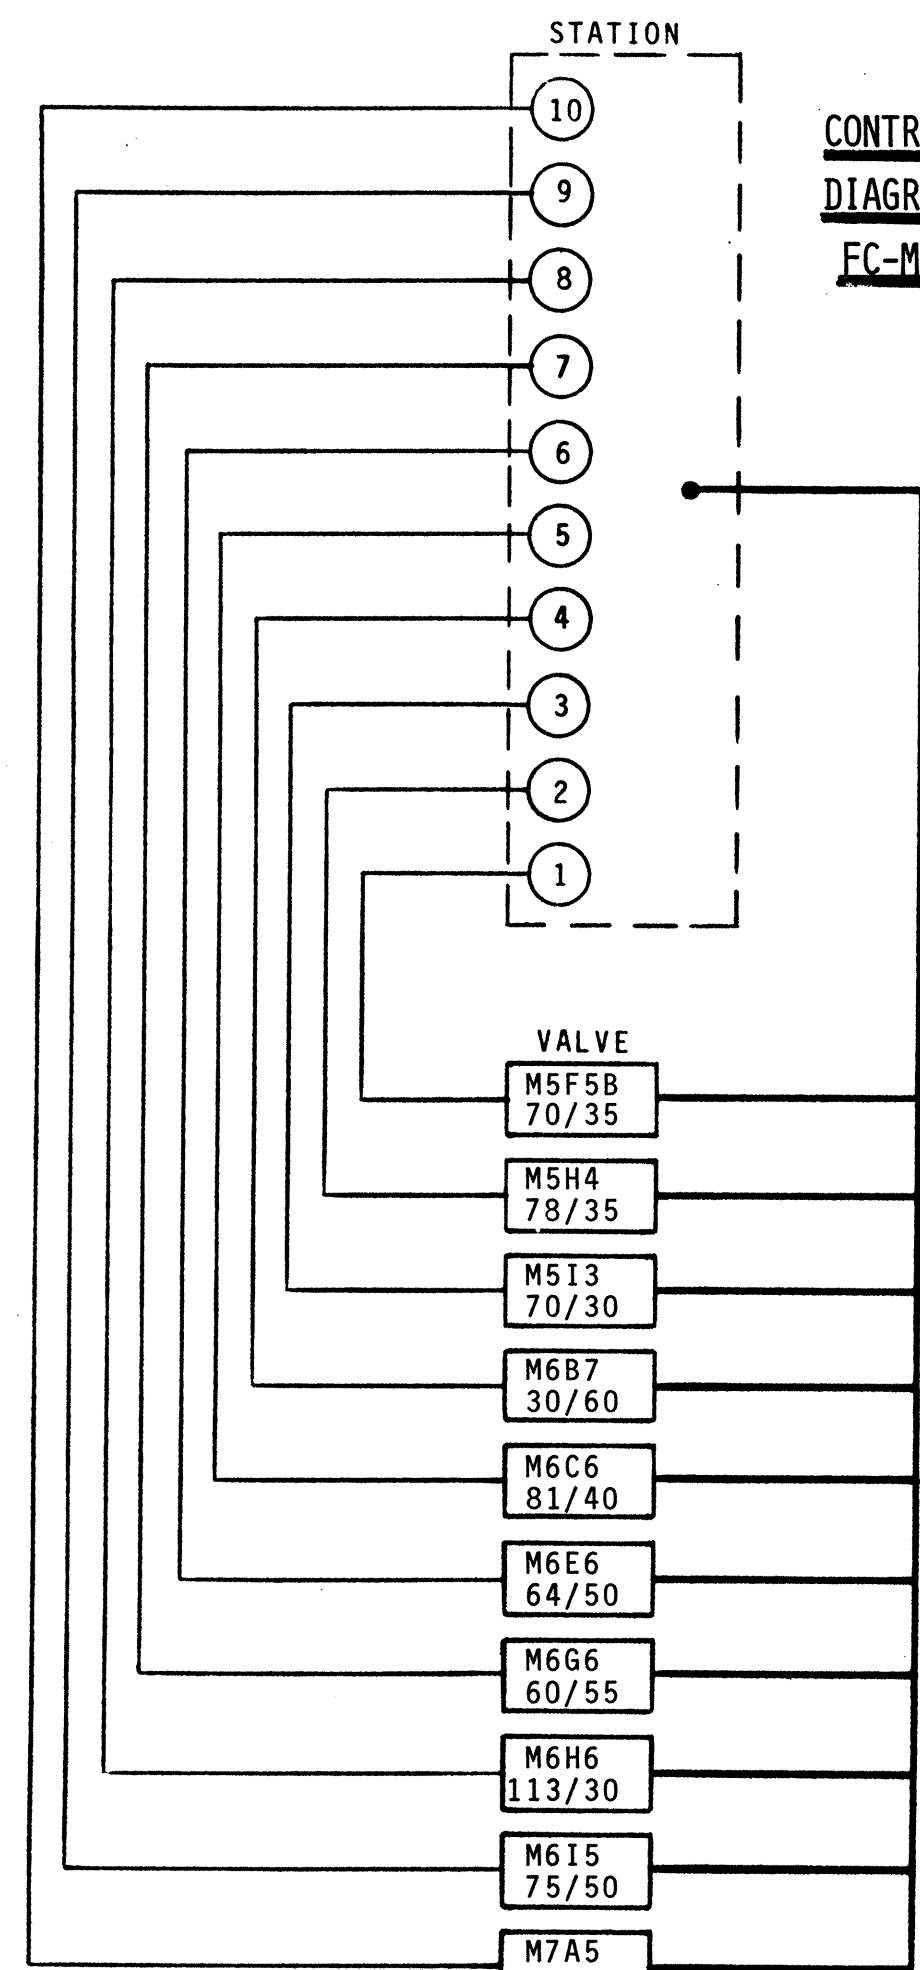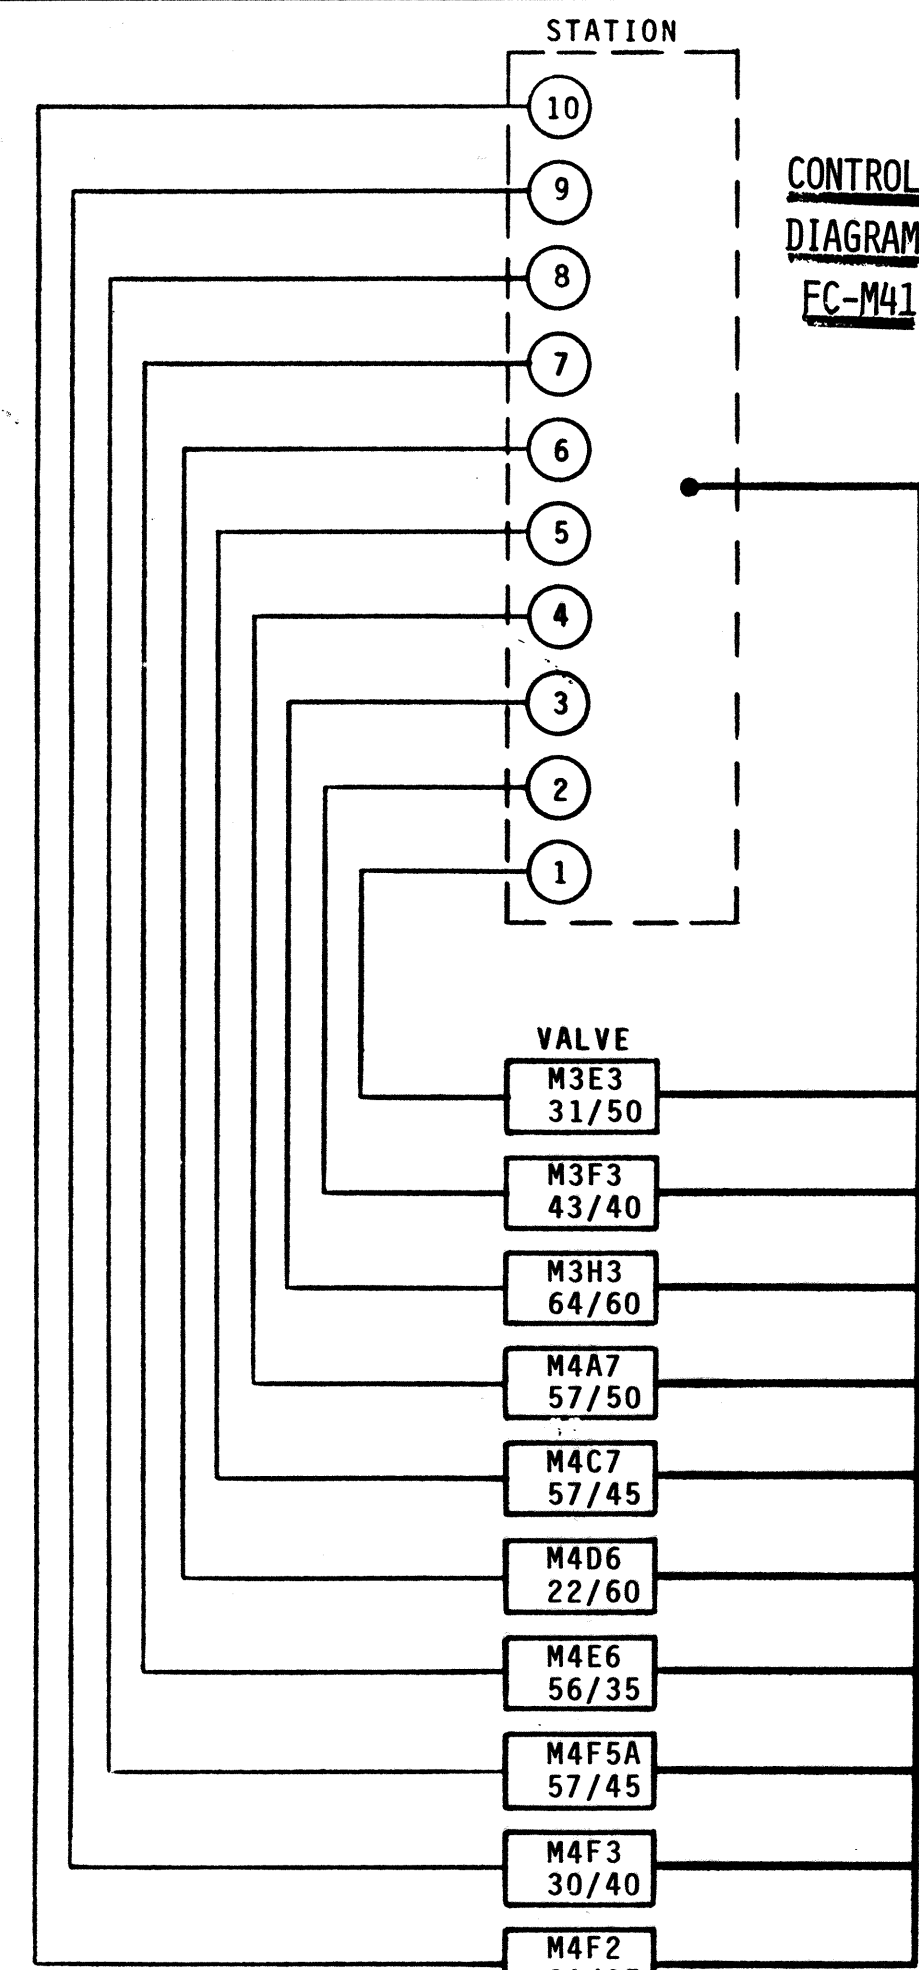

SPRINKLER BANK WHERE VALVE IS LOCATED



DISCHARGE OF BANK (GPM)

DURATION (MIN.)

EXPLANATION OF VALVE IDENTIFICATION

M3E3 31/50

ISOMETRIC - DISTRIBUTION SYSTEM
MILILANI INTERCHANGE
N.T.S.

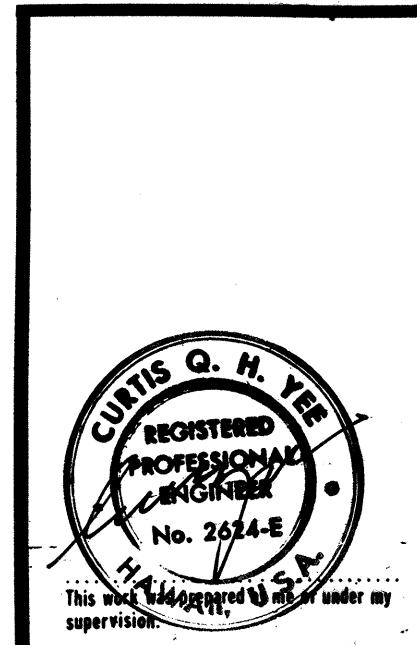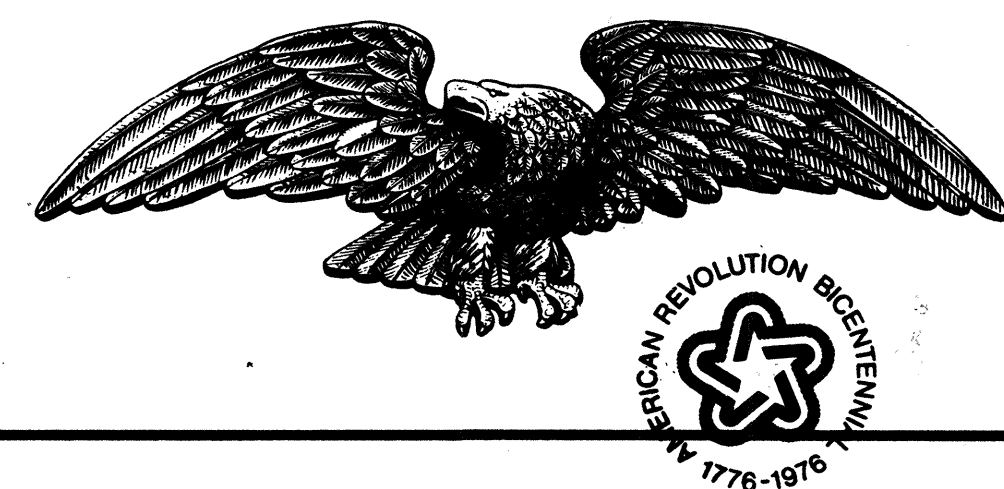

STATE OF HAWAII
DEPARTMENT OF TRANSPORTATION
HIGHWAYS DIVISION

PROJECT NO. I-H2-1(13):4

MILILANI INTERCHANGE
CONTROL DIAGRAMS


SHEET No. 18 OF 25 SHEETS

DATE	
SURVEY PLANNED BY	
DRAWN BY	
CHECKED BY	
NOTED BY	
.....	


FED. ROAD DIST. NO.	STATE	FED. AID PROJ. NO.	FISCAL YEAR	SHEET NO.	TOTAL SHEETS
HAWAII	HAW.	I-42-1(13)4	1977	28	34

- O RELAY COIL
 H N.O. CONTACT
 # N.C. CONTACT
 X INDICATING LIGHT
 CR CONTROL RELAY
 TD TIME DELAY RELAY (OFF DELAY)
 FS FLOW SWITCH
 OL OVERLOAD
 M MOTOR STARTING COIL
 H-O-A HAND-OFF-AUTO SELECTOR SW.
 A AMBER
 B BLUE
 G GREEN
 R RED


- PUMP STARTING SHALL BE INITIATED BY FLOW SWITCH #1
- PUMP #1 SHALL BE THE LEAD PUMP w/PUMP #2 PROVIDING ADDITIONAL PUMPING UPON DEMAND
- PUMP #2 SHALL START FIRST ONLY WHEN PUMP #1 IS THE ONLY PUMP TO RUN DURING THE PRECEDING PUMPING SEQUENCE.
- ALL CONTROL DEVICES & STARTERS SHALL BE HOUSED IN A COMMON ENCLOSURE. PILOT LIGHTS & SELECTOR SWITCHES SHALL BE INSTALLED ON THE CABINET FRONT & CLEARLY IDENTIFIED w/LAMINATED PLASTIC LABELS.
- CONTROL RELAYS SHALL BE 4-POLE, 300V MAGNETIC RELAYS w/CONVERTIBLE 240V CONTACTS & 120V COIL.
- TIME DELAY RELAY SHALL BE PNEUMATIC TIMERS w/OFF DELAY, 2-N.O. & 2-N.C. CONTACTS, 120V COIL, TIMING RANGE 0.2 TO 180 SECONDS
- INDICATING LIGHTS SHALL BE FULL VOLTAGE TYPE, 120V, w/COLORED LENS.
- SELECTOR SWITCH SHALL BE 3-POSITION MAINTAINED w/CAMS, CONTACT BLOCKS & OPERATING KNOB.

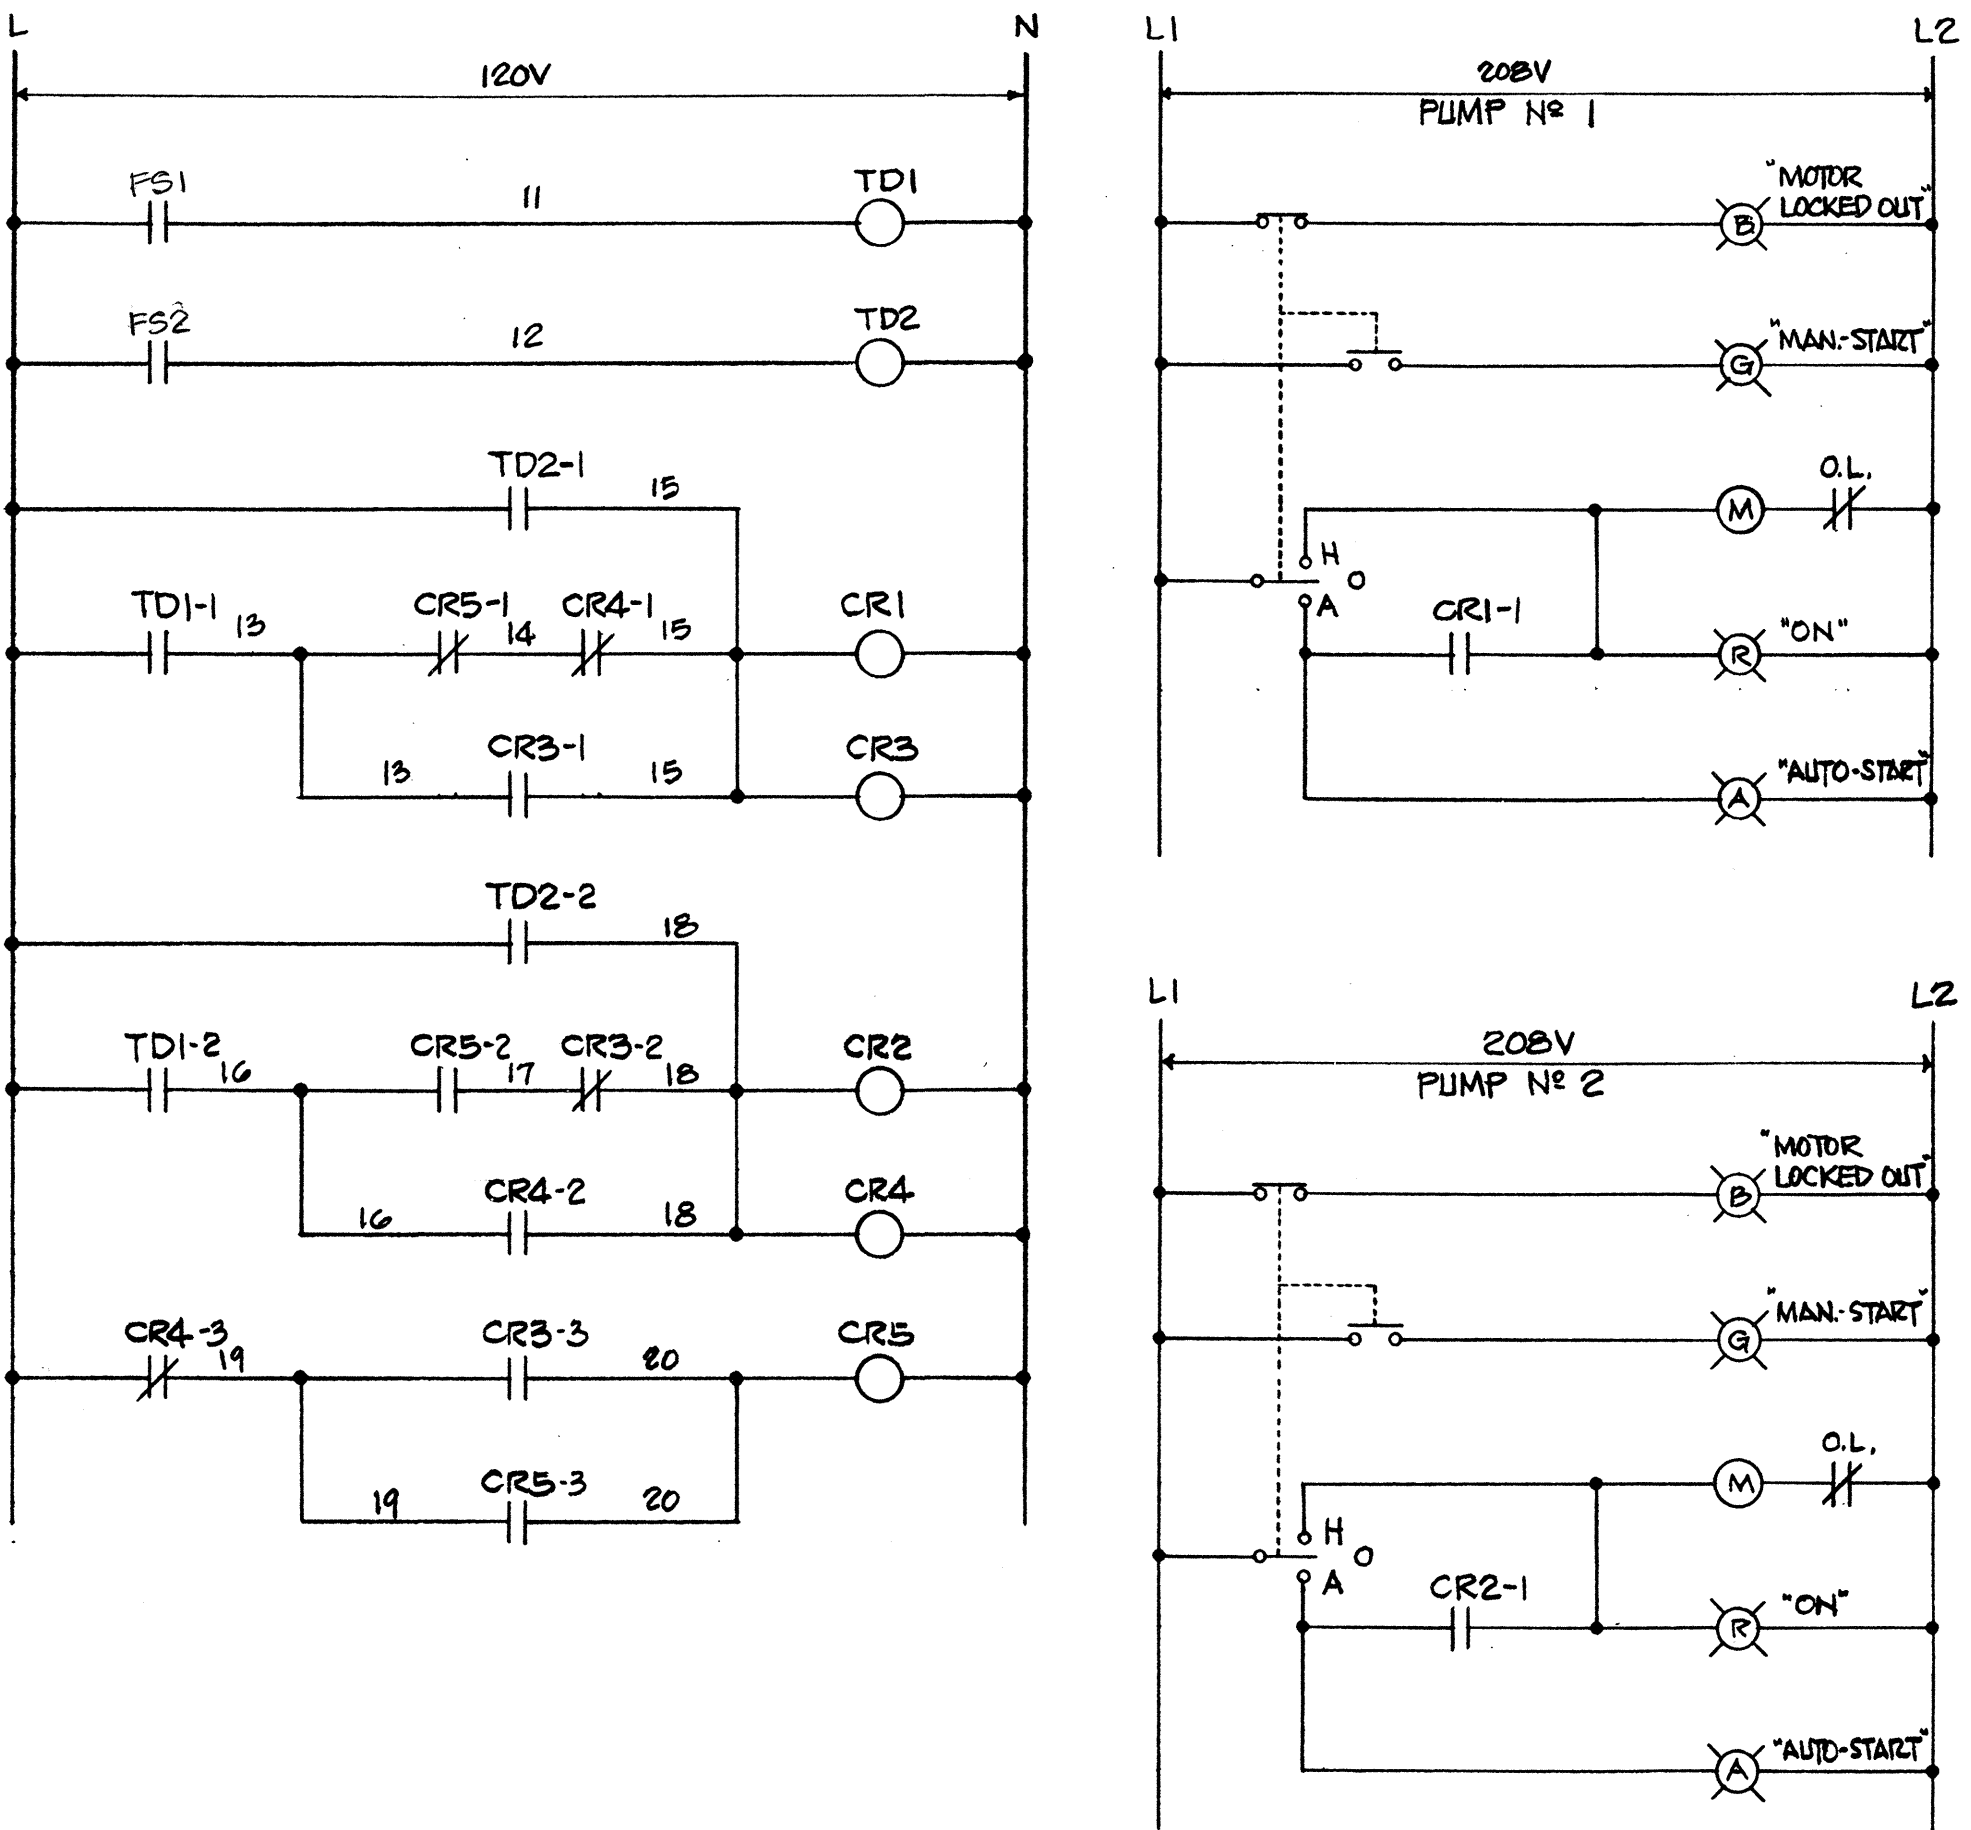


F 19 PUMP CONTROL SCHEMATIC

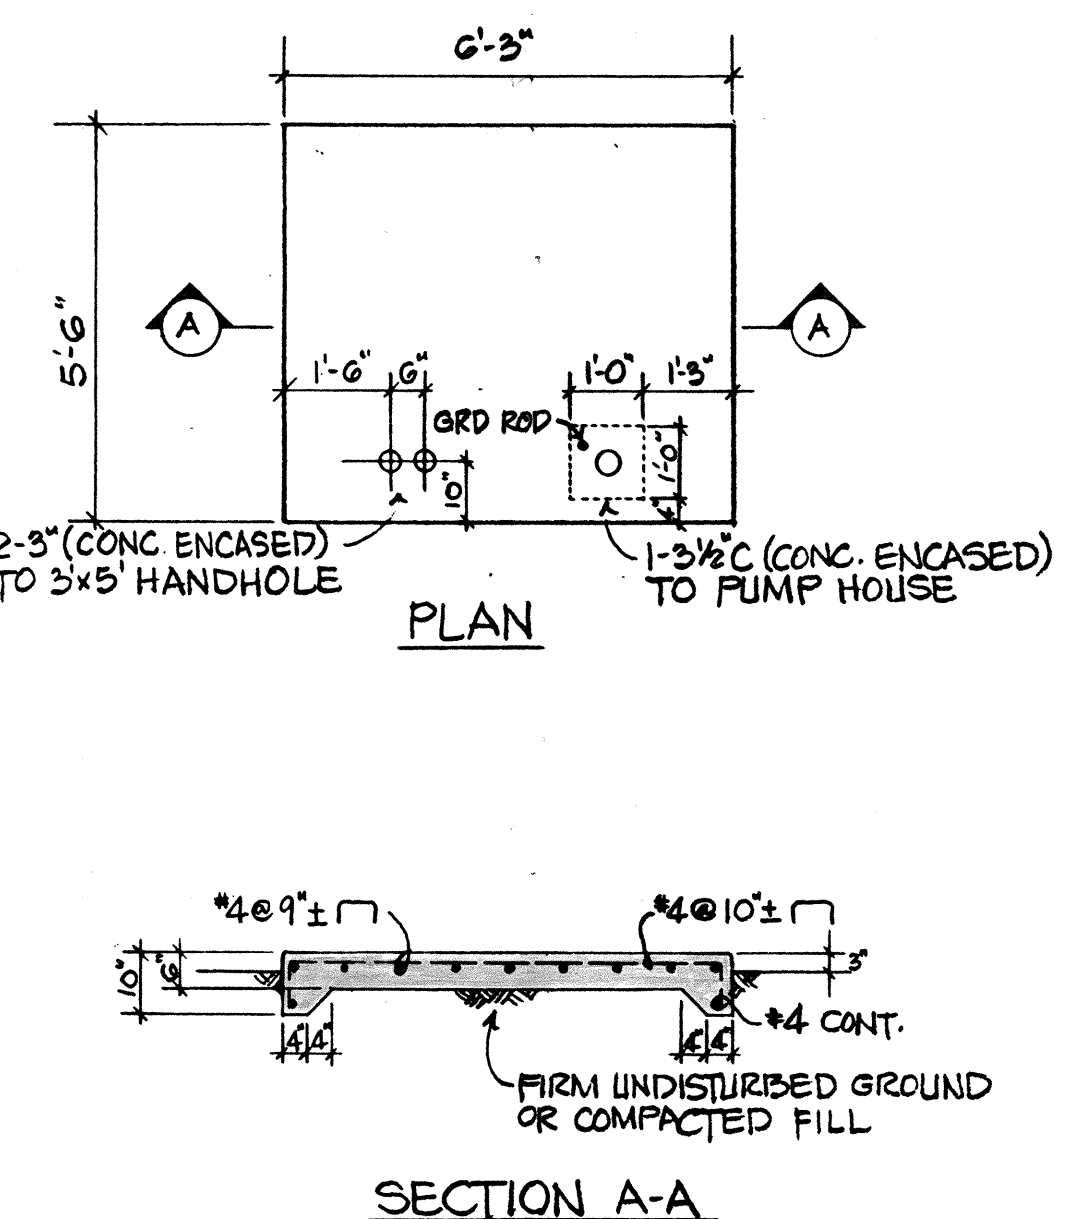


A 19 TRANSFORMER PAD DETAIL
SCALE: 3/8" = 1'-0"

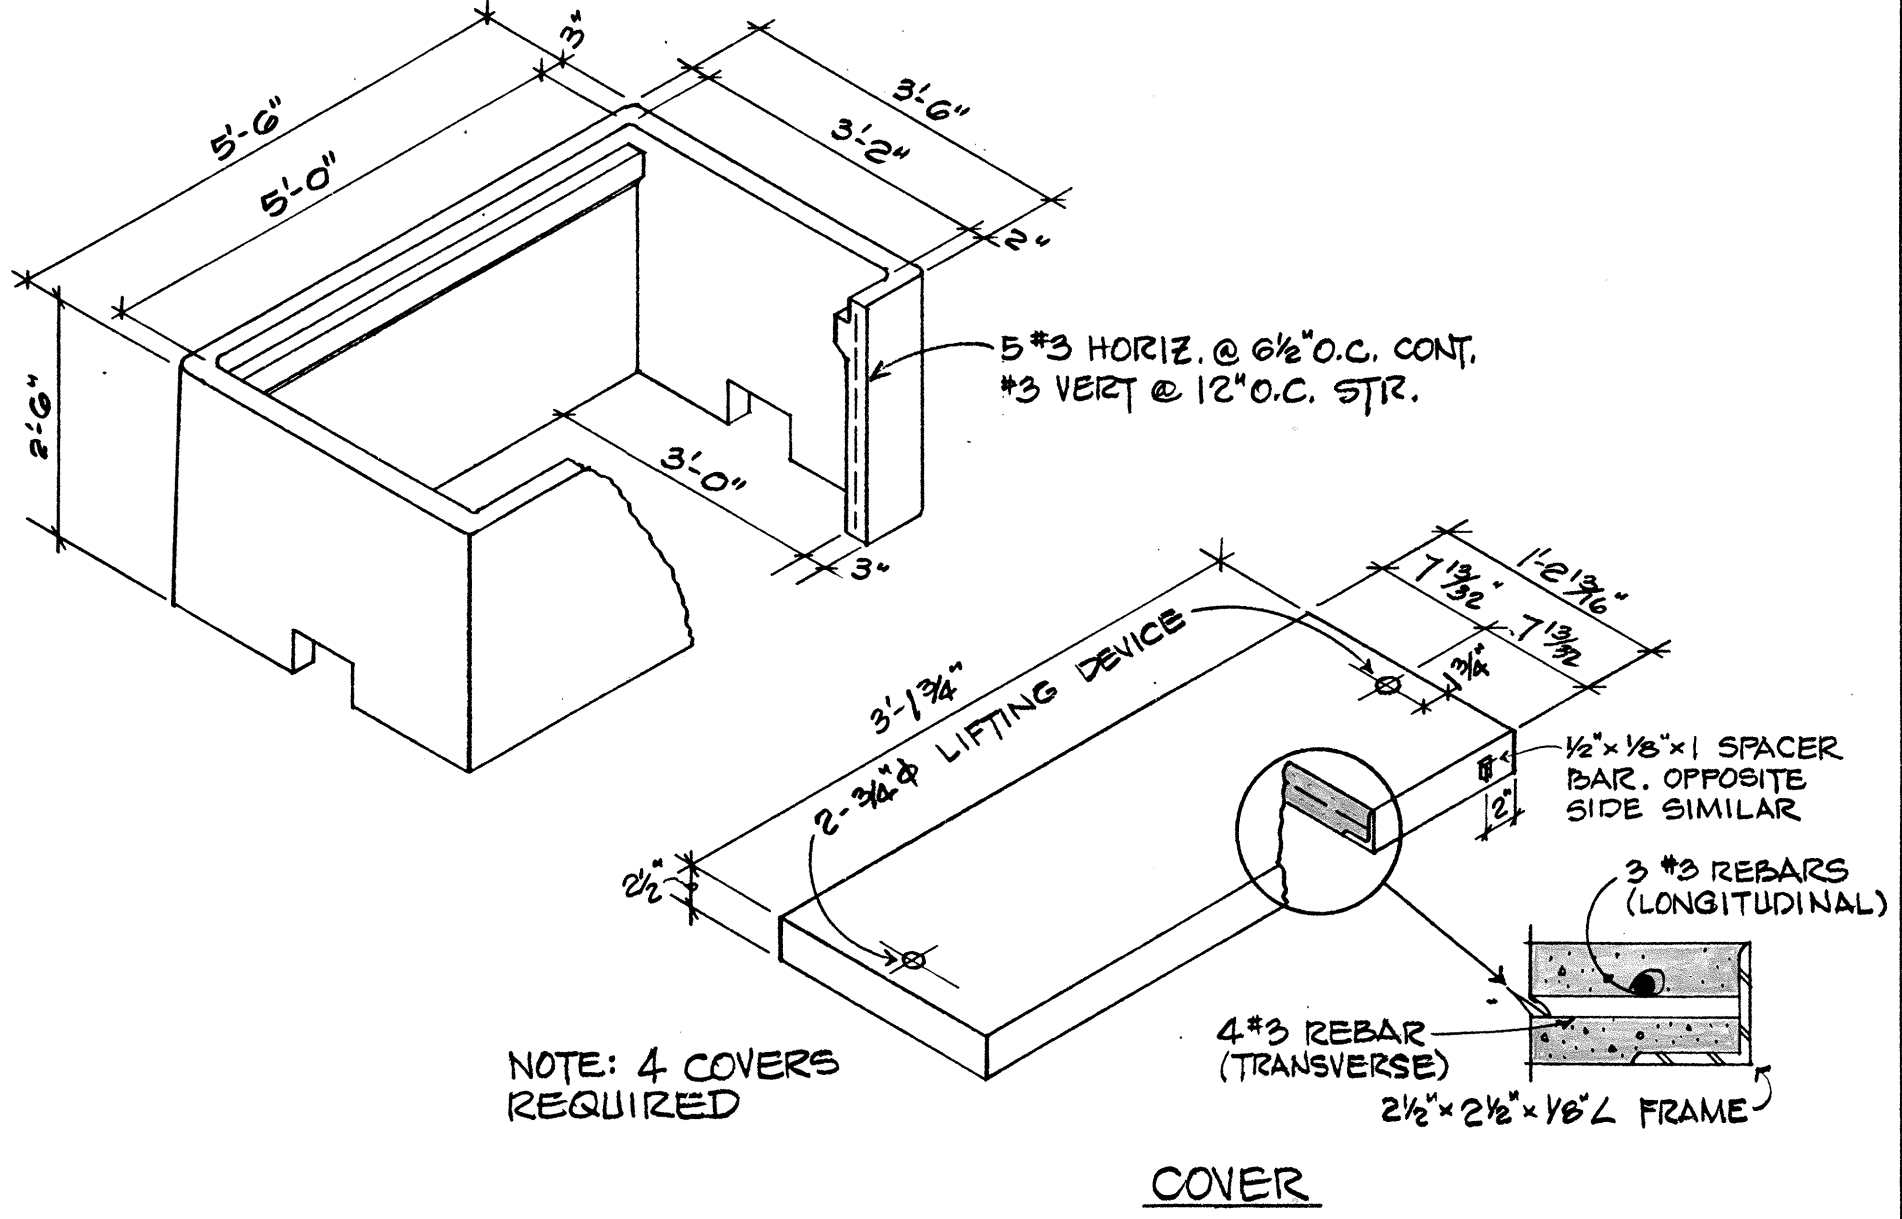


B 19 HANDHOLE DETAILS
NOT TO SCALE

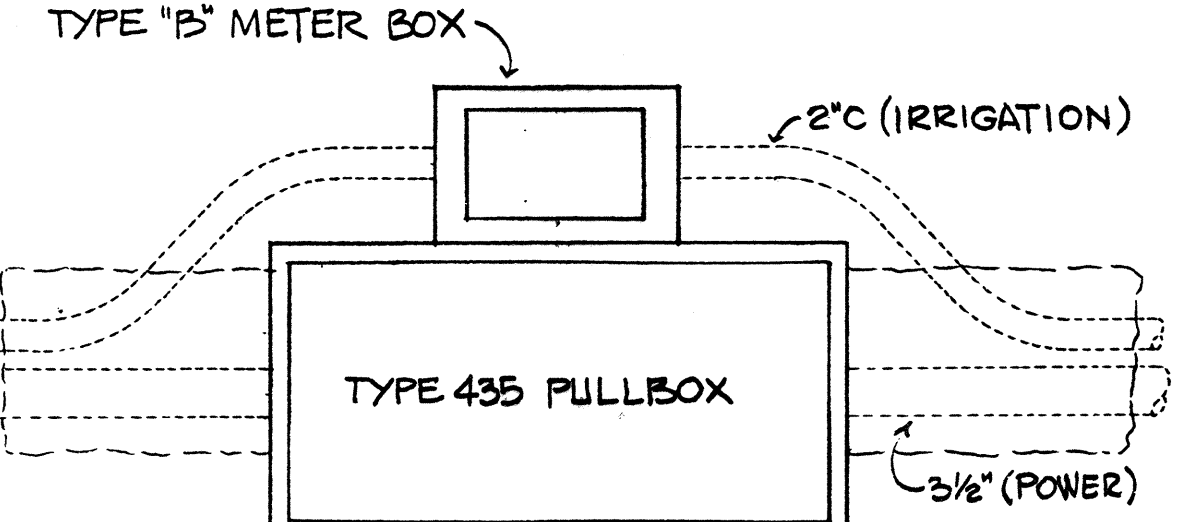


C 19 PULLBOX PLAN
NOT TO SCALE

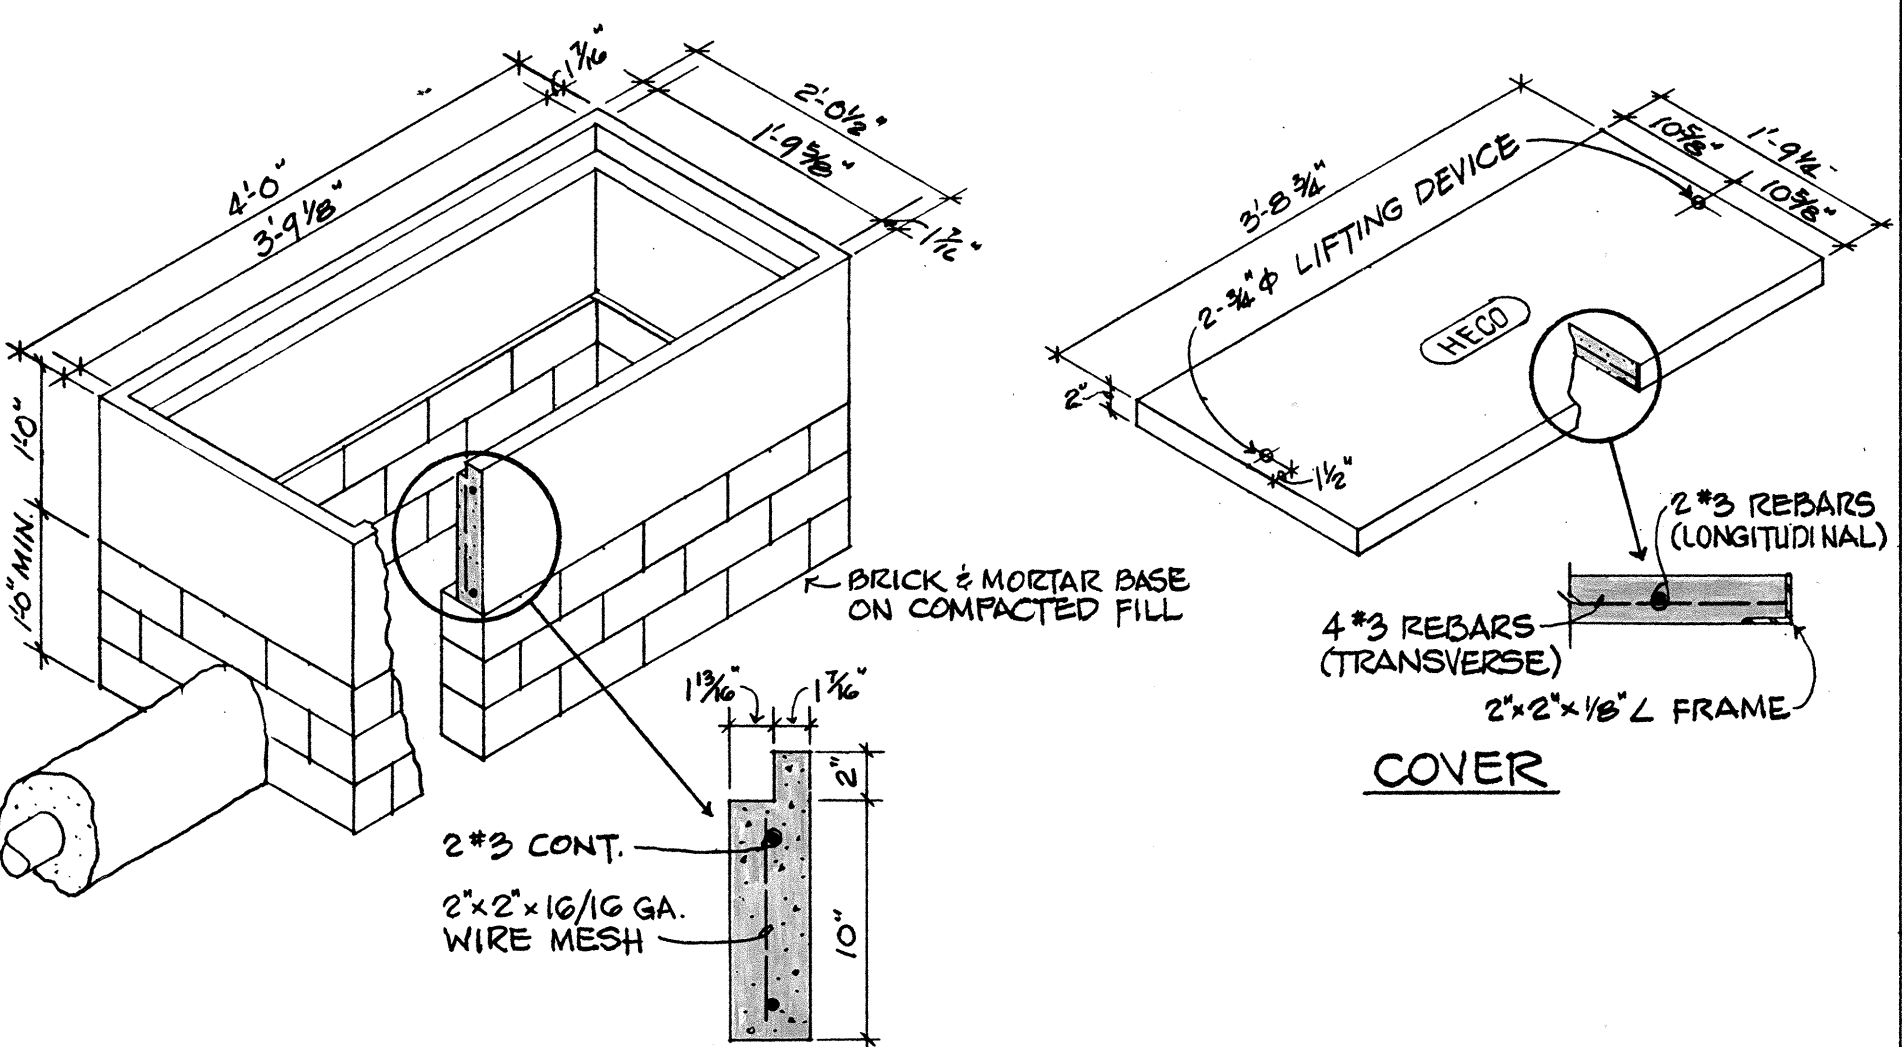

D 19 TYPE 435 PULLBOX DETAILS
NOT TO SCALE

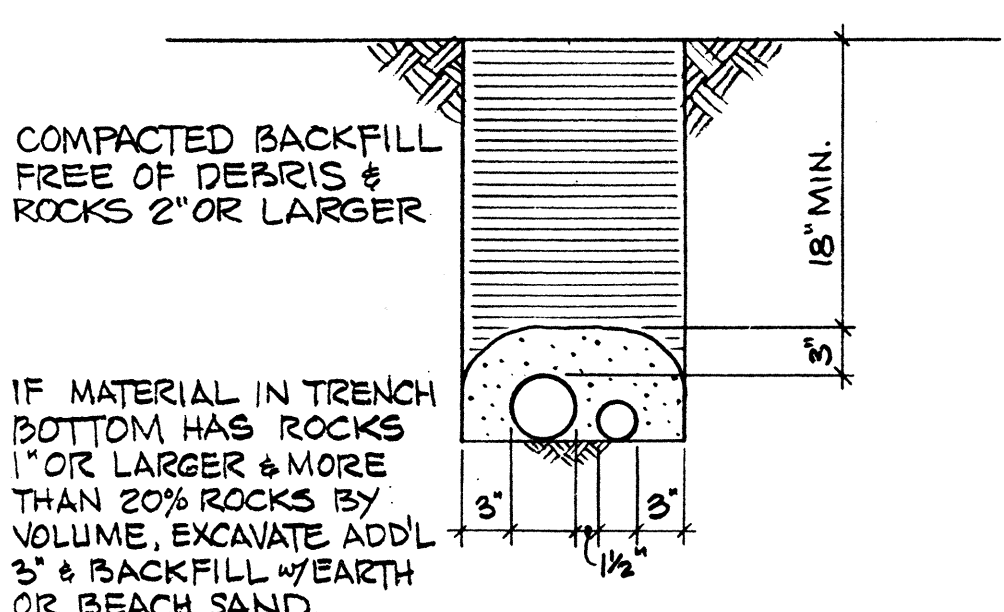


E 19 DUCTLINE SECTION
NOT TO SCALE

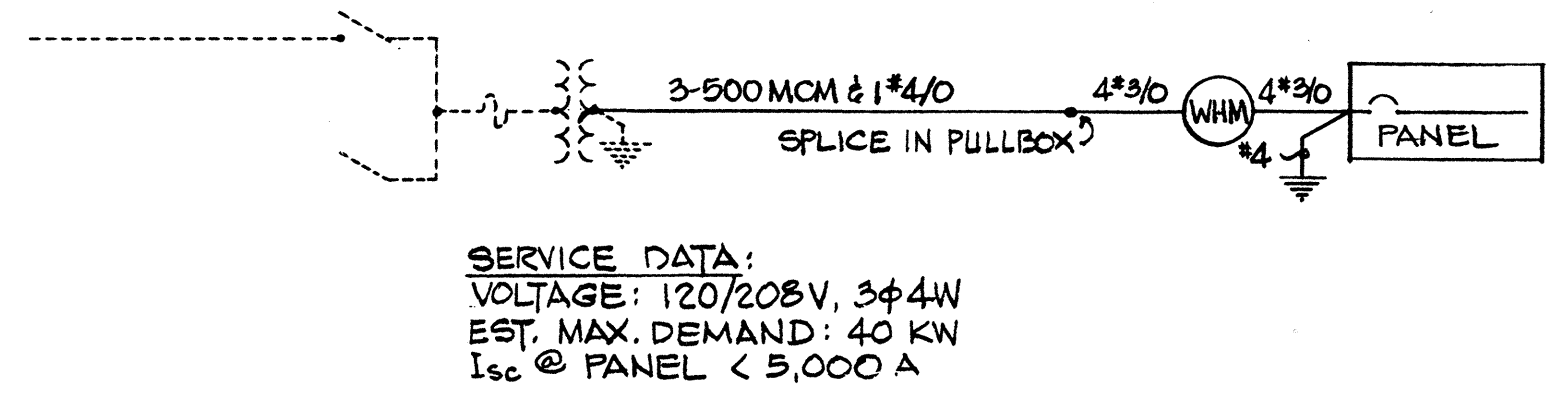


E 19 ONE LINE DIAGRAM

SURVEY PLOTTED BY	DATE
DESIGNED BY	
TRACED BY	
NOTED BY	
CHECKED BY	
ORIGINAL PLAN	
NOTE BOOK	
No.	

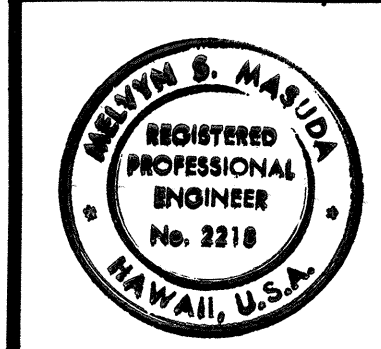


STATE OF HAWAII
 DEPARTMENT OF TRANSPORTATION
 HIGHWAYS DIVISION
 PROJECT NO. I-42-1(13)4
 MILILANI INTERCHANGE
 ELECTRICAL DETAILS

FED. ROAD DIST. NO.	STATE	FED. AID PROJ. NO.	FISCAL YEAR	SHEET NO.	TOTAL SHEETS
HAWAII	HAW.	I-H2-1(13):4	1977	29	34

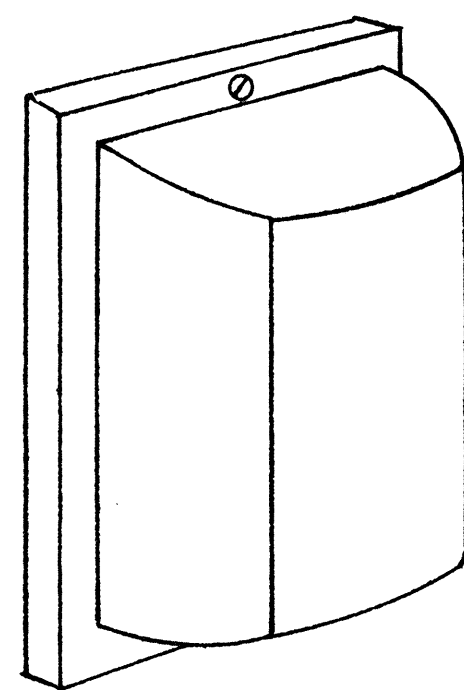

TYPE "B" FIXTURE

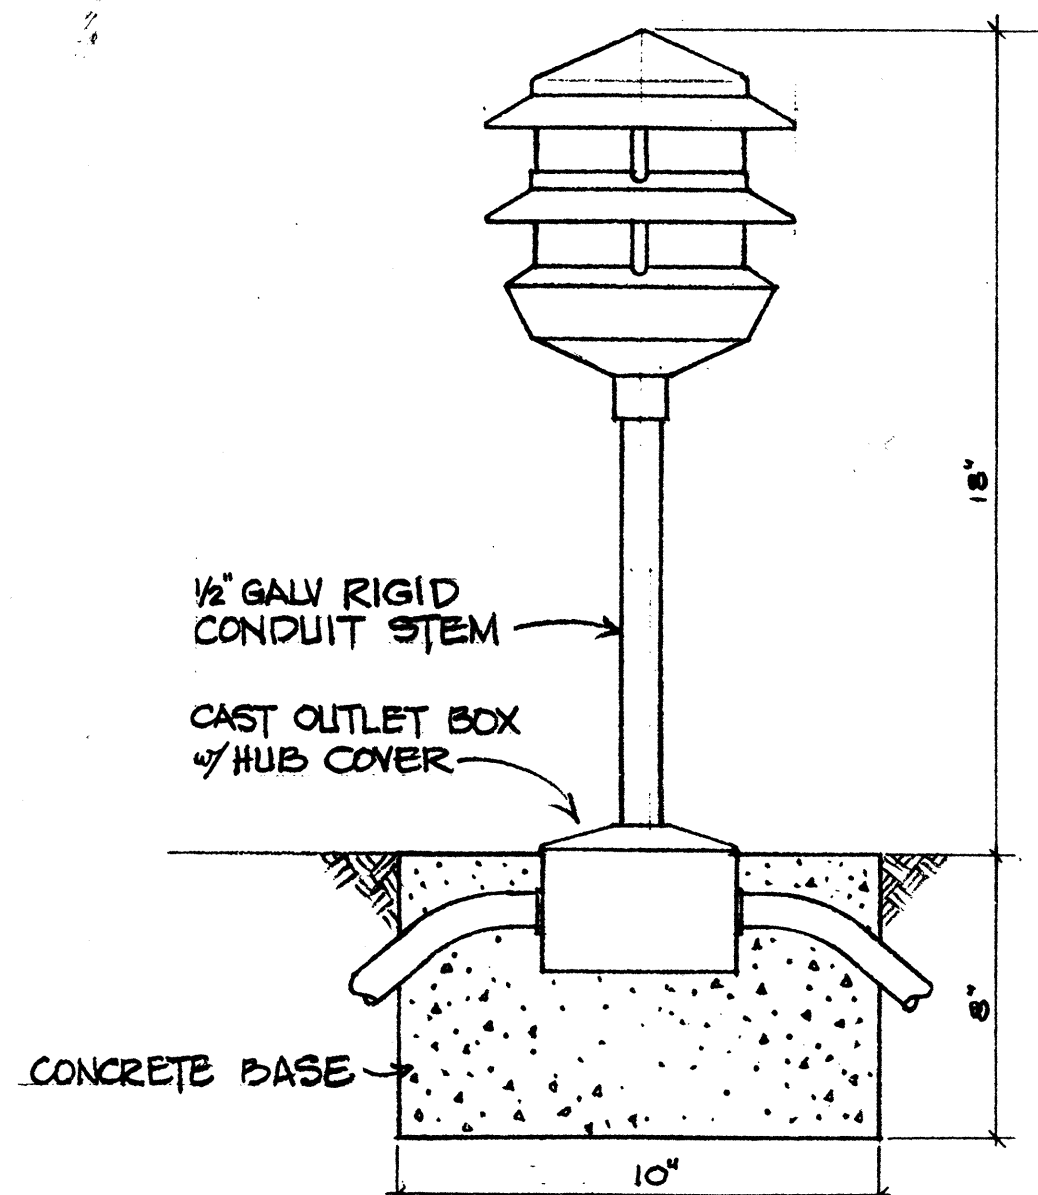


TYPE "C" FIXTURE


A 20 LIGHTING FIXTURE DETAILS
NOT TO SCALE

PANEL SCHEDULE									
120/208 VOLTS, 3-PHASE, 4-WIRE, SOLID NEUTRAL									
175A MAIN BREAKER									
INDUSTRIAL - BOLTED, SURFACE									
CKT NO	BREAKER	USE	L-TS	R-ROPT	S-SPACE	KVA ALLOWED			WIRE SIZE
1	2	3	4	5	6	A	B	C	
1	1	20	R			1.0			12
2			L			0.5			
3							0.6		
4							0.5		12
5			S					1.0	
6	1	20	S					1.0	
7	3	100	PUMP NO 1			6.5	6.5	6.5	4
8	1	100	PUMP NO 2			6.5	6.5	6.5	4
9	1	20	PFB			1.0	1.0	1.0	
10	3	20	PFB			1.0	1.0	1.0	
TOTALS						16.5	16.1	17.0	
KVA ALLOWED						49.6			
DEMAND FACTOR						0.8			
DEMAND KVA						39.7			


LIGHTING FIXTURE SCHEDULE		
TYPE	LAMP DATA	DESCRIPTION
(A)	1-48"RS F40 CW	FLUOR STRIP, BAKED WHITE ENAMEL FINISH, 120V HPF BALLAST.
(B)	1-GOW A-19/IF	INCAND WALL BRACKET, INJECTION-MOLDED, UV-STABILIZED, UNBREAKABLE THERMOPLASTIC LENS, GASKETED, 1/2" STEEL BACK PLATE.
(C)	1-GOW A-19/IF	INCAND, DIE-CAST ALUMINUM HOUSING & LAMPS, GASKETED VAPORTIGHT GLOBE
(D)		
(E)		

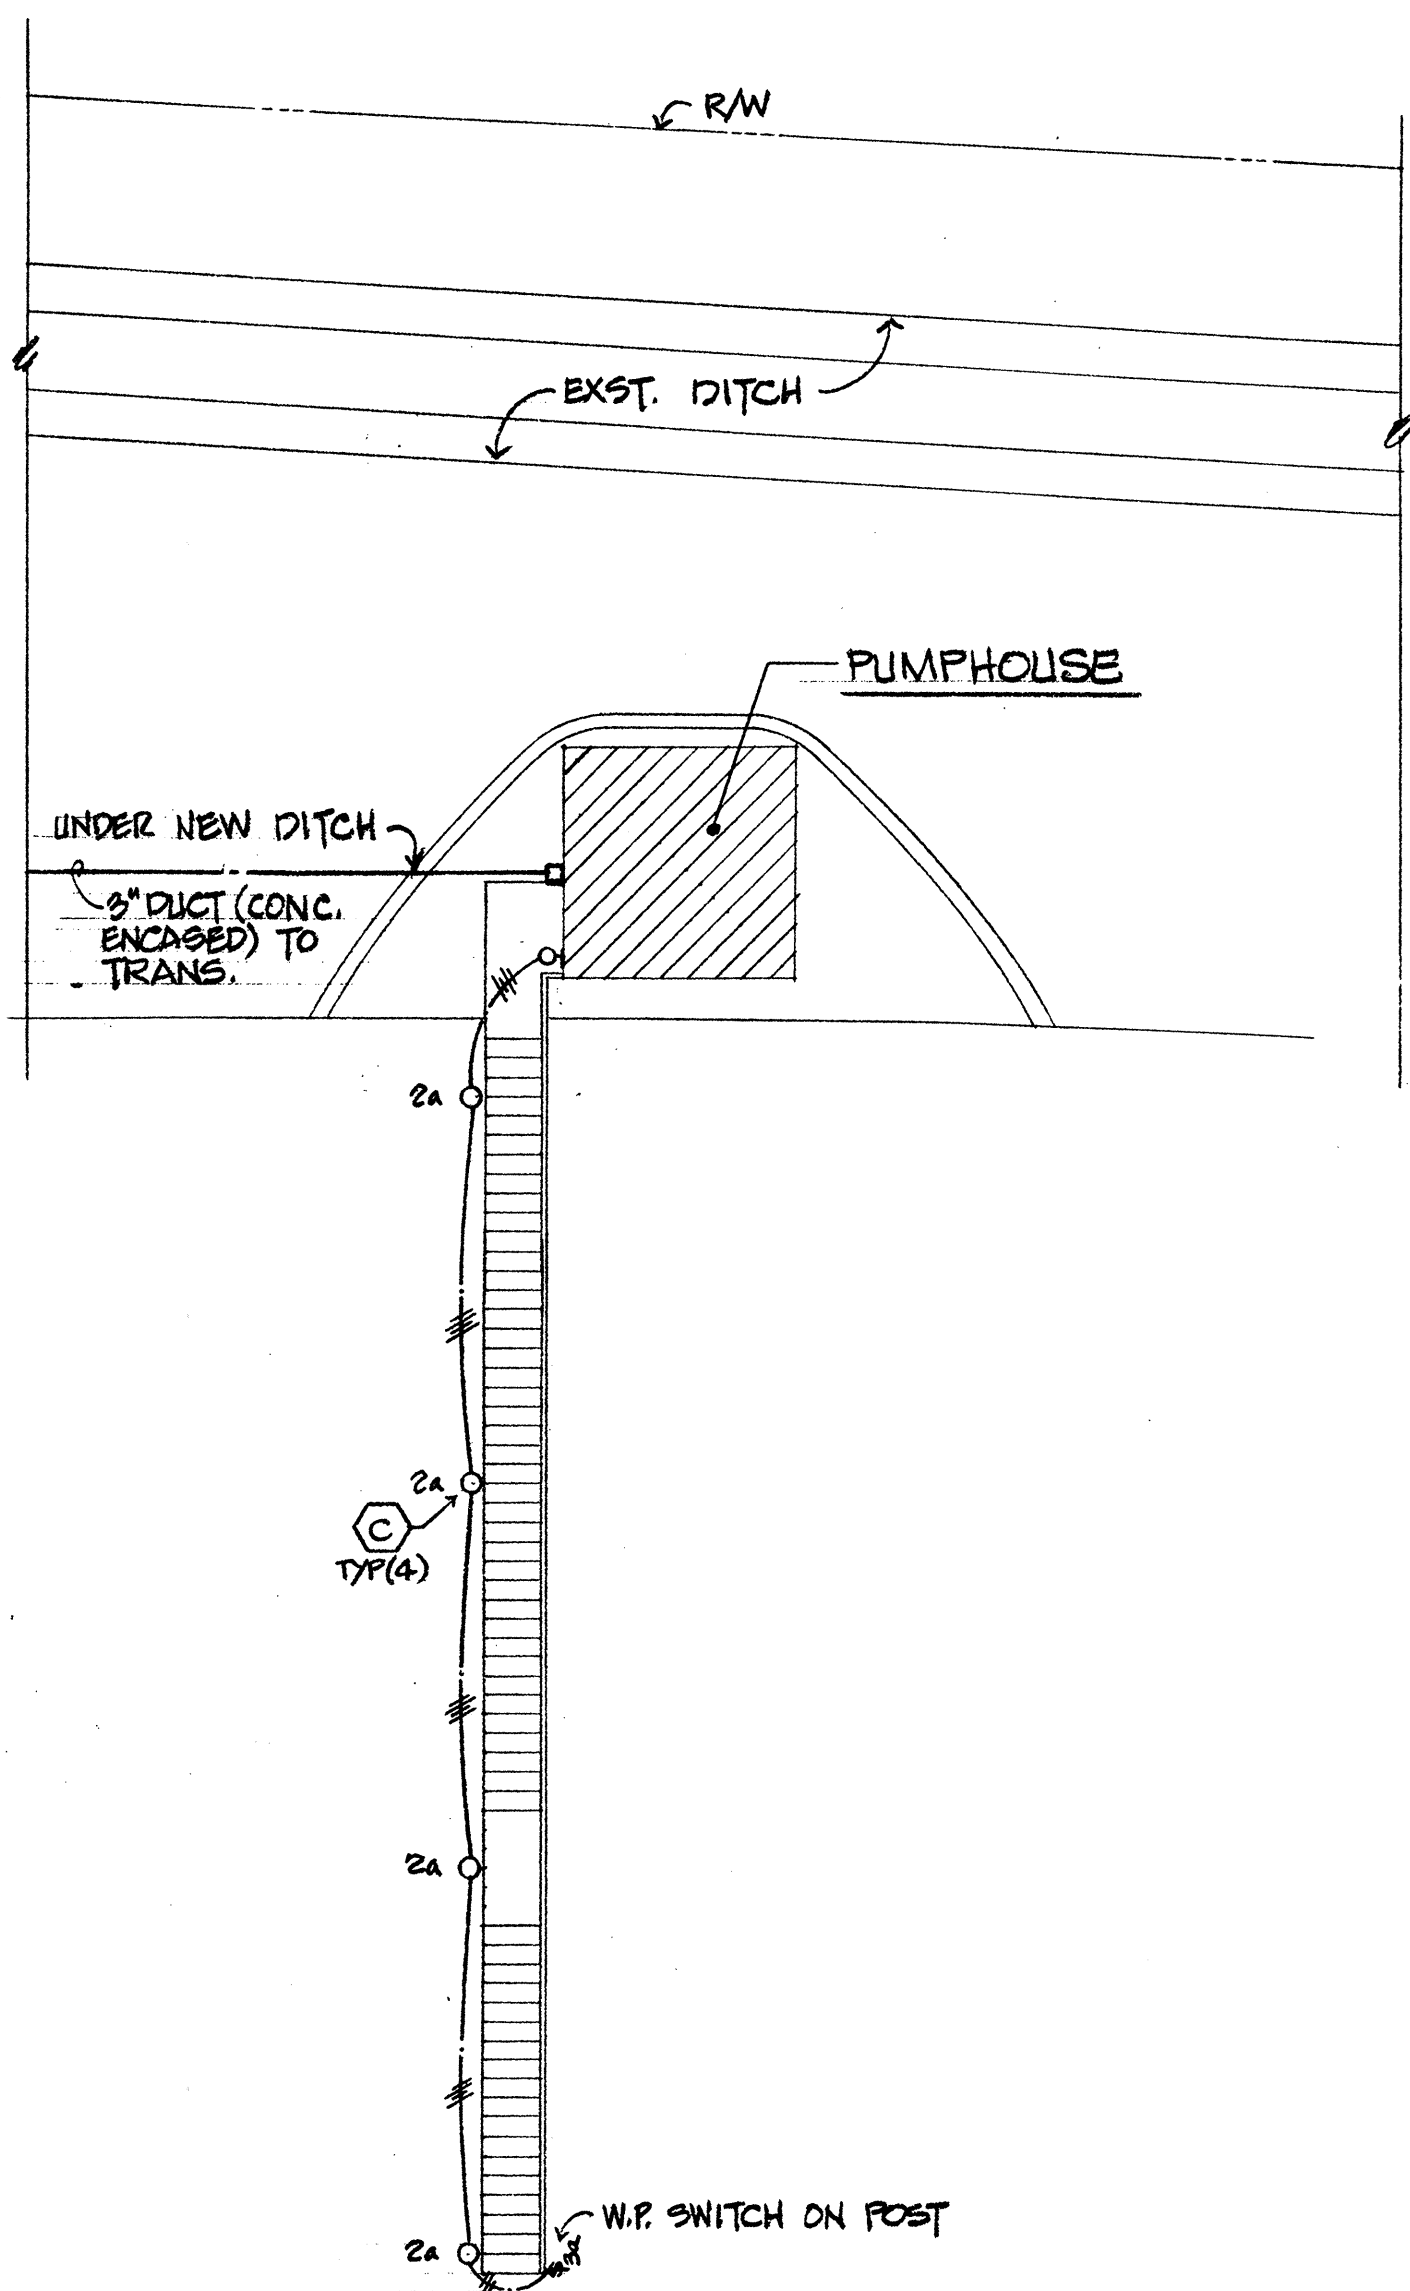

C 20 PUMPHOUSE EXTERIOR ELECTRICAL PLAN
SCALE: 1" = 10'

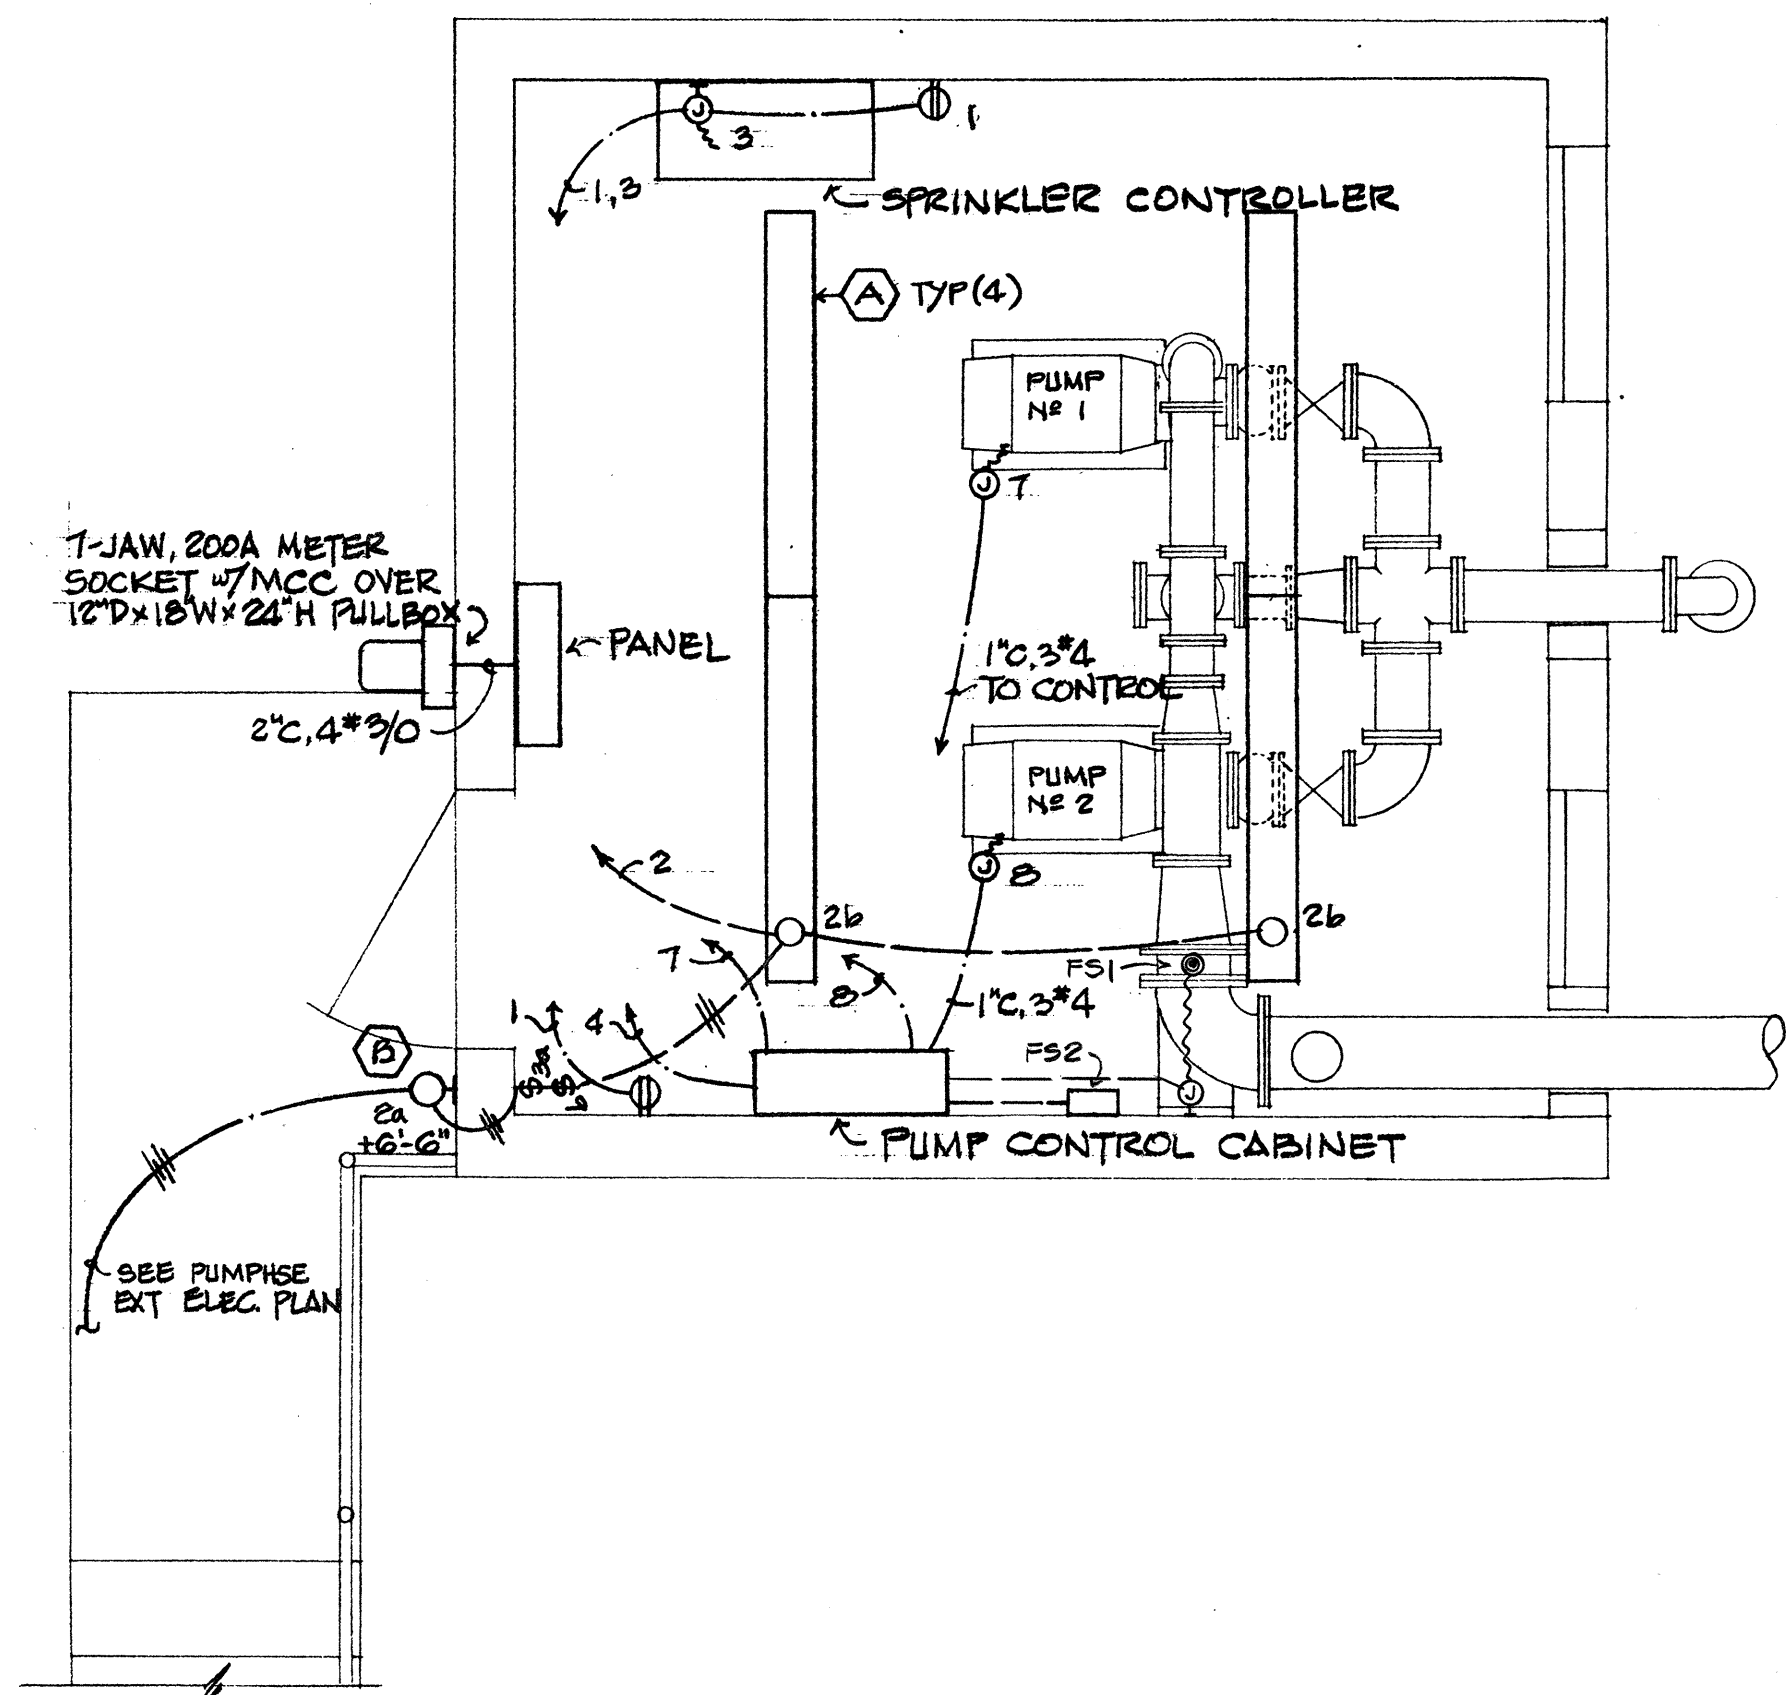


D 20 PUMPHOUSE ELECTRICAL PLAN
SCALE: 1/2" = 1'-0"

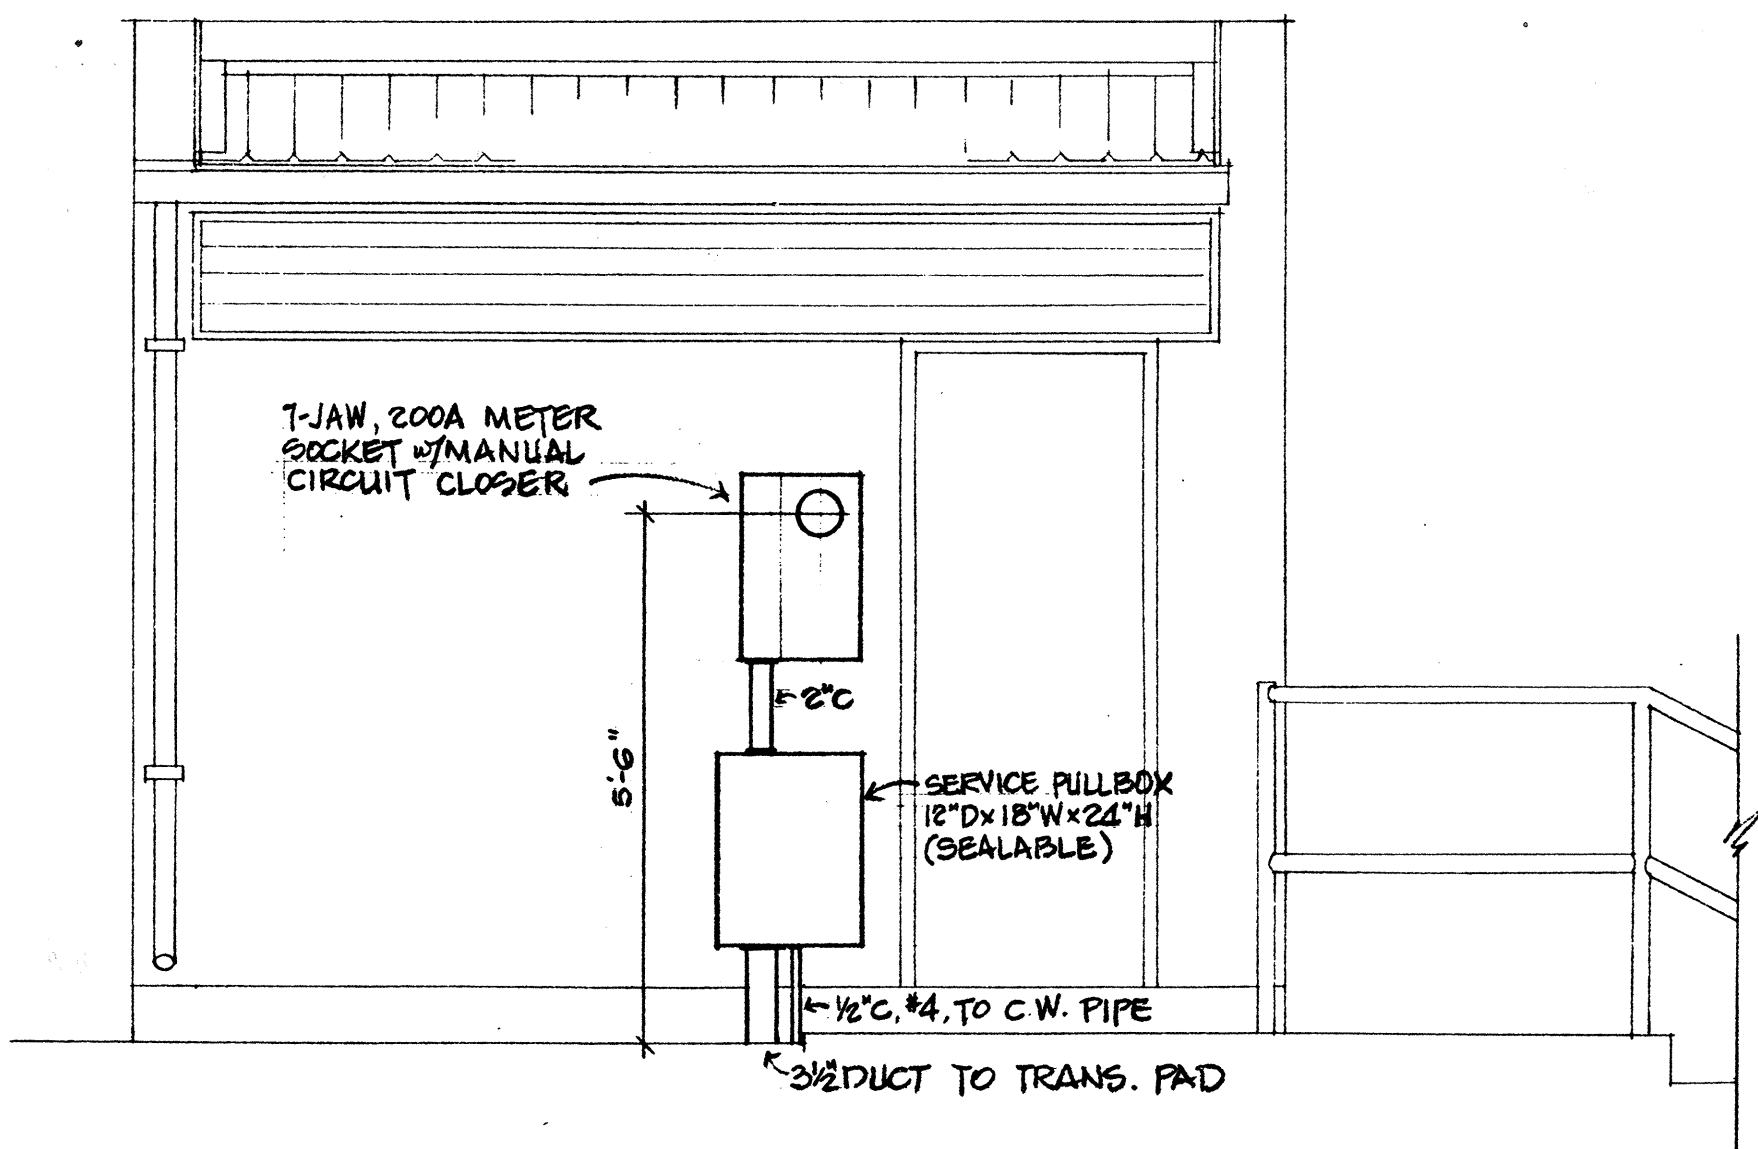

B 20 SERVICE EQUIPMENT ELEVATION
SCALE: 1/2" = 1'-0"

DATE	_____
SURVEY PLOTTED BY	_____
DRAWN BY	_____
DESIGNED BY	_____
NOTED BY	_____
CHECKED BY	_____
ORIGINAL PLAN	_____
NOTE BOOK	_____
QUANTITIES BY	_____
CHECKED BY	_____

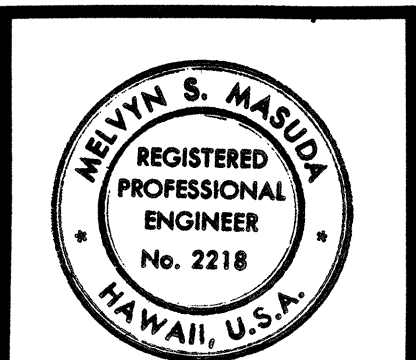

STATE OF HAWAII
DEPARTMENT OF TRANSPORTATION
HIGHWAYS DIVISION

PROJECT NO. I-H2-1(13):4

MILILANI INTERCHANGE
ELECTRICAL DETAILS

SHEET No. 20 OF 25 SHEETS

FED. ROAD DIST. NO.	STATE	FED. AID PROJ. NO.	FISCAL YEAR	SHEET NO.	TOTAL SHEETS
HAWAII	HAW.	I-H2-1(13):4	1977	31	34

ORIGINAL PLAN	SURVEY PLOTTED BY _____	DATE _____
NOTE BOOK	DRAWN BY _____	_____
	TRACED BY _____	_____
	DESIGNED BY _____	_____
	QUANTITIES BY _____	_____
No. _____	CHECKED BY _____	_____

EXPLANATION OF SYSTEM NO. DESIGNATIONS

INTERCHANGE SYMBOL: W - WAHIAWA
SHEET L - LEILEHUA
M - MILILANI

W 2 B 3 A

DESIGNATION USED WHEN MORE THAN
ONE SYSTEM IN GRID ZONE.

AREA NO. GRID ZONE COORDINATES

.....
This work was prepared by me or under my
supervision.

SHEET No. 22 OF 25 SHEETS

FED. ROAD DIST. NO.	STATE	FED. AID PROJ. NO.	FISCAL YEAR	SHEET NO.	TOTAL SHEETS
HAWAII	HAW.	I-H2-1 (13): 4	1977	32	34

ORIGINAL PLAN	SURVEY PLOTTED BY _____	DATE _____
NOTE BOOK	DRAWN BY _____	" _____
	TRACED BY _____	" _____
	DESIGNED BY _____	" _____
	QUANTITIES BY _____	" _____
No. _____	CHECKED BY _____	" _____

EXPLANATION OF SYSTEM NO. DESIGNATIONS

INTERCHANGE SYMBOL: W - WAHIATA
SHEET L - LEILEHUA
M - MILILANI

W 2 B 3 A
AREA NO. DESIGNATION USED WHEN MORE THAN
ONE SYSTEM IN GRID ZONE.
GRID ZONE COORDINATES

ADD 32

FED. ROAD DIST. NO.	STATE	FED. AID PROJ. NO.	FISCAL YEAR	SHEET NO.	TOTAL SHEETS
HAWAII	HAW.	I-H2-1(13):4	1977	33	34

ORIGINAL PLAN	SURVEY PLOTTED BY _____	DATE _____
NOTE BOOK	DRAWN BY _____	"
	TRACED BY _____	"
	DESIGNED BY _____	"
No. _____	QUANTITIES BY _____	"
	CHECKED BY _____	"

EXPLANATION OF SYSTEM NO. DESIGNATIONS

INTERCHANGE SYMBOL: W - WAHAHUA
SHEET L - LEILEHUA
M - MILILANI

W 2 B 3 A DESIGNATION USED WHEN MORE THAN
ONE SYSTEM IN GRID ZONE,
AREA NO. GRID ZONE COORDINATES

.....
This work was prepared by me or under my supervision.

SHEET No. 24 OF 25 SHEETS

ADD 33

FED. ROAD DIST. NO.	STATE	FED. AID PROJ. NO.	FISCAL YEAR	SHEET NO.	TOTAL SHEETS
HAWAII	HAW.	I-H-2-1(13):4	1977	34	34

EXPLANATION OF SYSTEM NO. DESIGNATIONS

DESIGNATES INTERCHANGE SYMBOL: W - WAHIAWA
DRIP SYS SHEET L - LEILEHUA
D W 2 B 3 A M - MILILANI

DESIGNATION USED WHEN MORE THAN
ONE SYSTEM IN GRID ZONE.
AREA NO. GRID ZONE COORDINATES

**STATE OF HAWAII
DEPARTMENT OF TRANSPORTATION
HIGHWAYS DIVISION**

PROJECT NO. I-H2-1(13):4

MILILANI INTERCHANGE

SPRINKLER SUMMARY

SHEET No. 25 OF 25 SHEETS