	· · · · · · · · · · · · · · · · · · ·
	INDEX TO DRAWINGS
SHEET NO.	DESCRIPTION
1	TITLE SHEET
2	STANDARD PLANS SUMMARY
3-5	TYPICAL SECTIONS
6 - 14	ALIGNMENT
15 - 16	TRAFFIC CONTROL PLAN & NOTES
17 - 22	ROADWAY CONSTRUCTION & NOTES
23 - 30 *	DRAINAGE & GRADING
31 - 38	SIGNING & PAVEMENT MARKINGS
39 - 40	TRAFFIC SIGNAL SYSTEM
41 - 55	ELECTRICAL PLANS
56 - 57	RETAINING WALL
58 - 84	CROSS SECTIONS
,	

* C.O. 29S-I, C.O. 29S-2, C.O. 30S-I NEW TOTAL SHEET COUNT = 87 SHEETS

CASTLE & COOKE RESIDENTIAL, INC.

P.O. BOX 2780 HONOLULU, HAWAII

"AS - BUILT"

CONSTRUCTION PLANS

FOR THE

NORTHBOUND ON- AND OFF-RAMPS


TO


INTERSTATE ROUTE H-2

AT

MILILANI INTERCHANGE PROJECT NO. H2-C-02-94

DISTRICT OF EWA

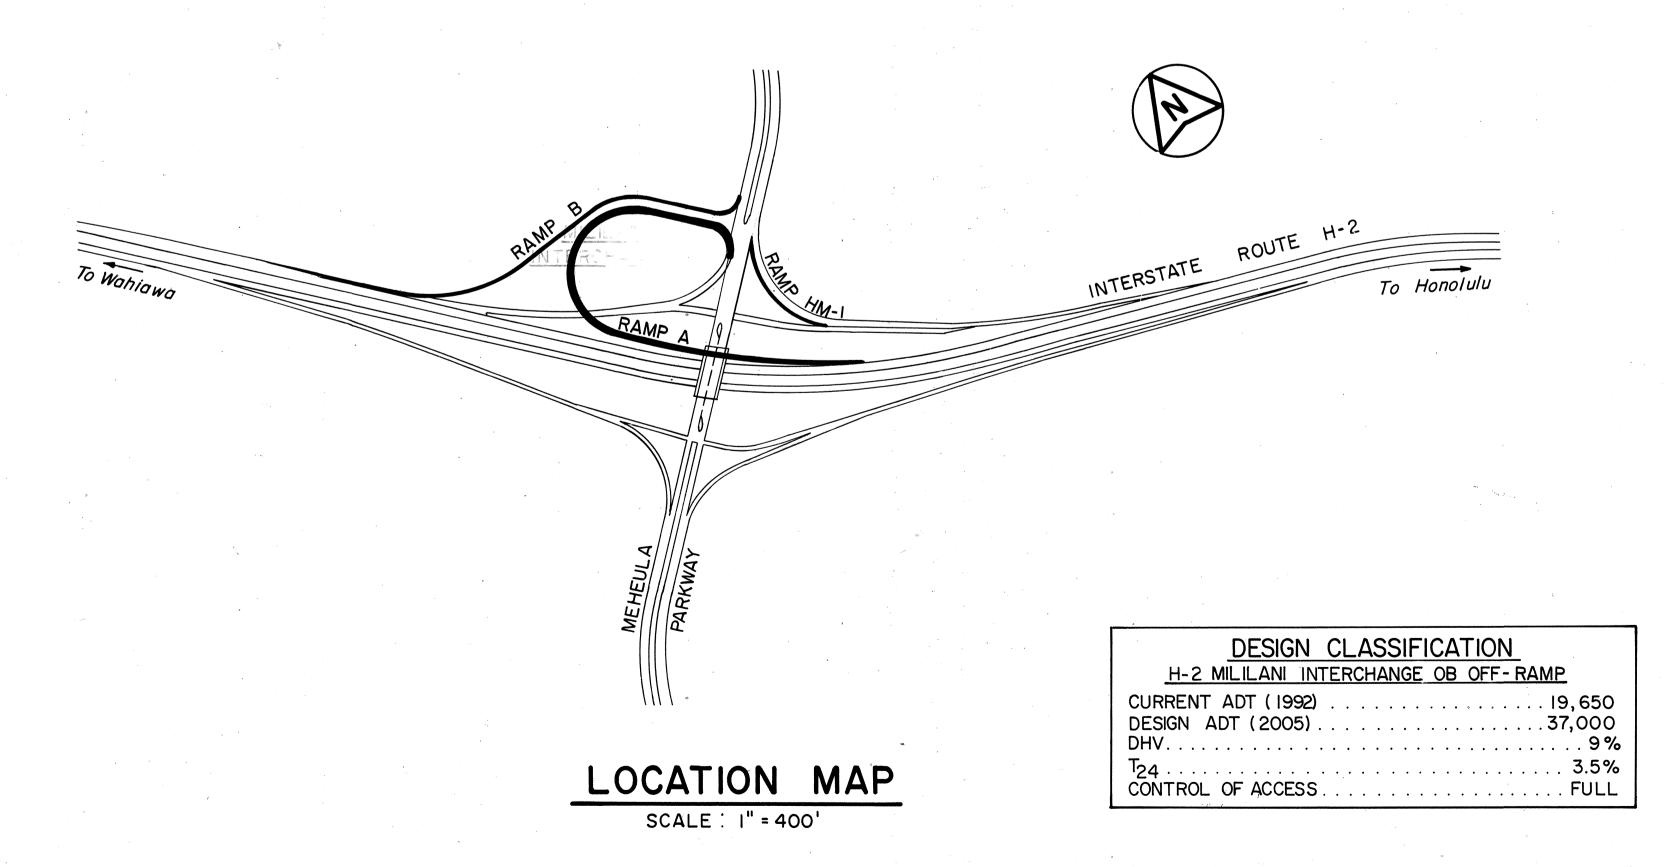

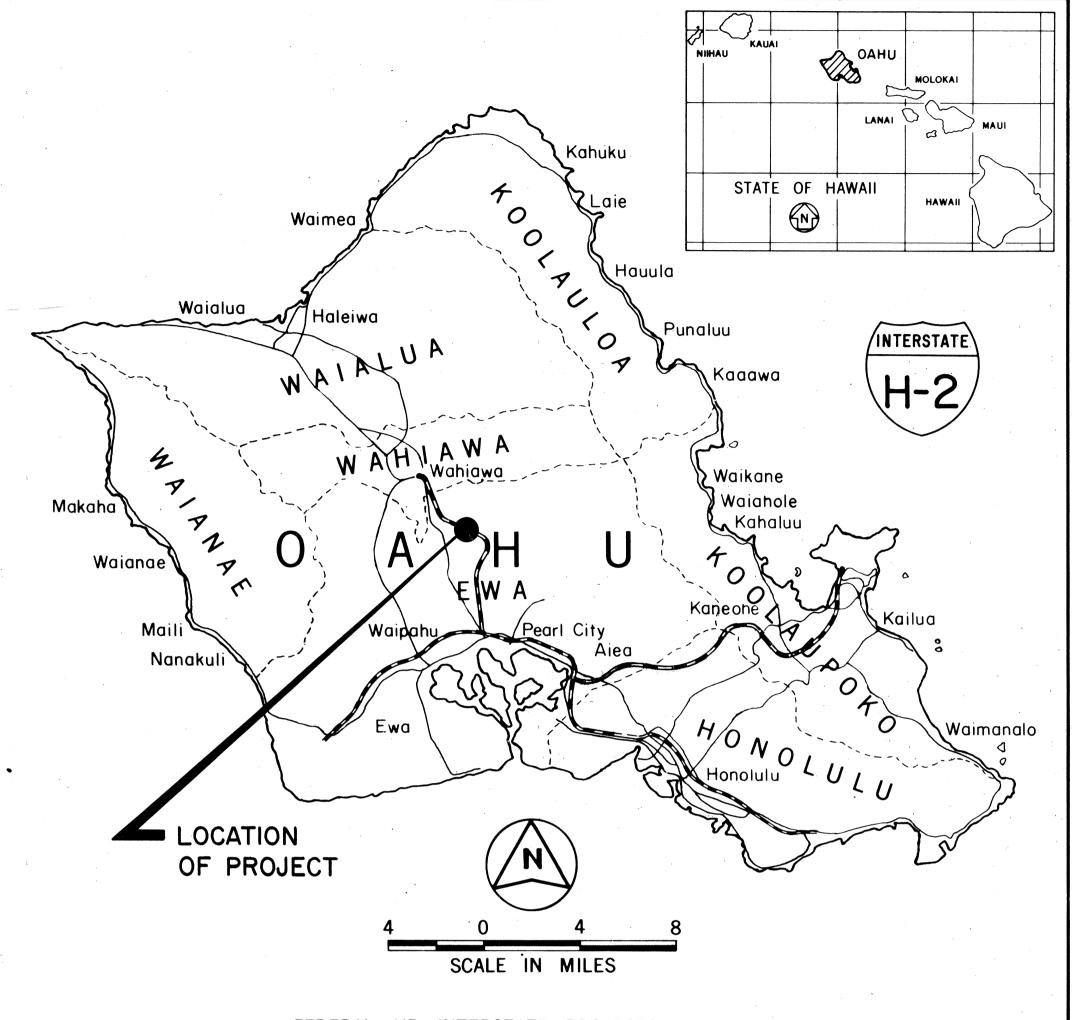

FED. ROAD DIST. NO. FISCAL SHEET TOTAL YEAR NO. SHEETS

FED. AID PROJ. NO.

PMT-H2-C-02-94

FEDERAL AID INTERSTATE PROJECTS PREVIOUSLY CONSTRUCTED OR UNDER CONSTRUCTION

APPROVED :

State Department of Transportation (Approval granted for work within State right-of-way only. ID No. 0-89-137 letter of approval No. HWY-CM 2.1920 dated 5/4/92)

ARSONS BRINCKERHOFF