**	INDEX TO PLANS
SHEET NO.	DESCRIPTION 6
	TITLE SHEET
2	KEY PLAN
3	MILESTONE SCHEDULE
4	GENERAL NOTES, ASSITEV. SYMBOLS & QUANTITIES
5	GENERAL PLAN & PROFILE
6	HALAMA APPROACH - INSTALLATION ACCESS
7	HAIKU APPROACH - INSTALLATION ACCESS
8	HALAMA PORTAL BUILDING I B-PLANS
9	HALAMA PORTAL BUILDING H B-PLAN & SECTIONS
, 10	HALAWA PORTAL BUILDING-O B-PLANS
11	HALAMA PORTAL BUILDING-08-PLAN & SECTIONS
12	HAIKU PORTAL BUILDING-I B-PLANS
13	HAIKU PORTAL BUILDING-I B-PLAN & SECTIONS
14	HAIKU PORTAL BUILDING-O B-PLANS
15	HAIRU PORTAL BUILDING-0 B-PLAN & SECTIONS
16	TUNNEL VENTILATION AIRFLOW DIAGRAM
17	TUNNEL VENTILATION EQUIPMENT SCHEDULES
18	TUNNEL VENTILATION INSTRUMENTATION DIAGRAM
19	SUPPLY FAN PLAN & SECTIONS
20	EXHAUST FAN PLAN & SECTION
21	EXHAUST FAN DETAILS
22	MISCELLANEOUS DETAILS
23	INTAKE & DISCHARGE DETAILS
24	ONE LINE DIAGRAM TYPICAL SUBSTATION

NO SUPPLEMENTARY SHEETS WERE ADDED TO THIS PROJECT AS A RESULT OF "AS-BUILT" POSTING. TOTAL SHEET COUNT AFTER "AS-BUILT" POSTING — 24 SHEETS.

STATE OF HAWAII

DEPARTMENT OF TRANSPORTATION

HIGHWAYS DIVISION

HONOLULU, HAWAII

"AS - BUILT"


PLANS FOR


CONSTRUCTION OF A PORTION OF

INTERSTATE ROUTE H-3

FURNISHING, DELIVERING, AND INSTALLING TUNNEL VENTILATION FANS AND ACCESSORIES FEDERAL AID INTERSTATE PROJECT NO. I-H3-I(60)

DISTRICTS OF KOOLAUPOKO AND EWA ISLAND OF OAHU

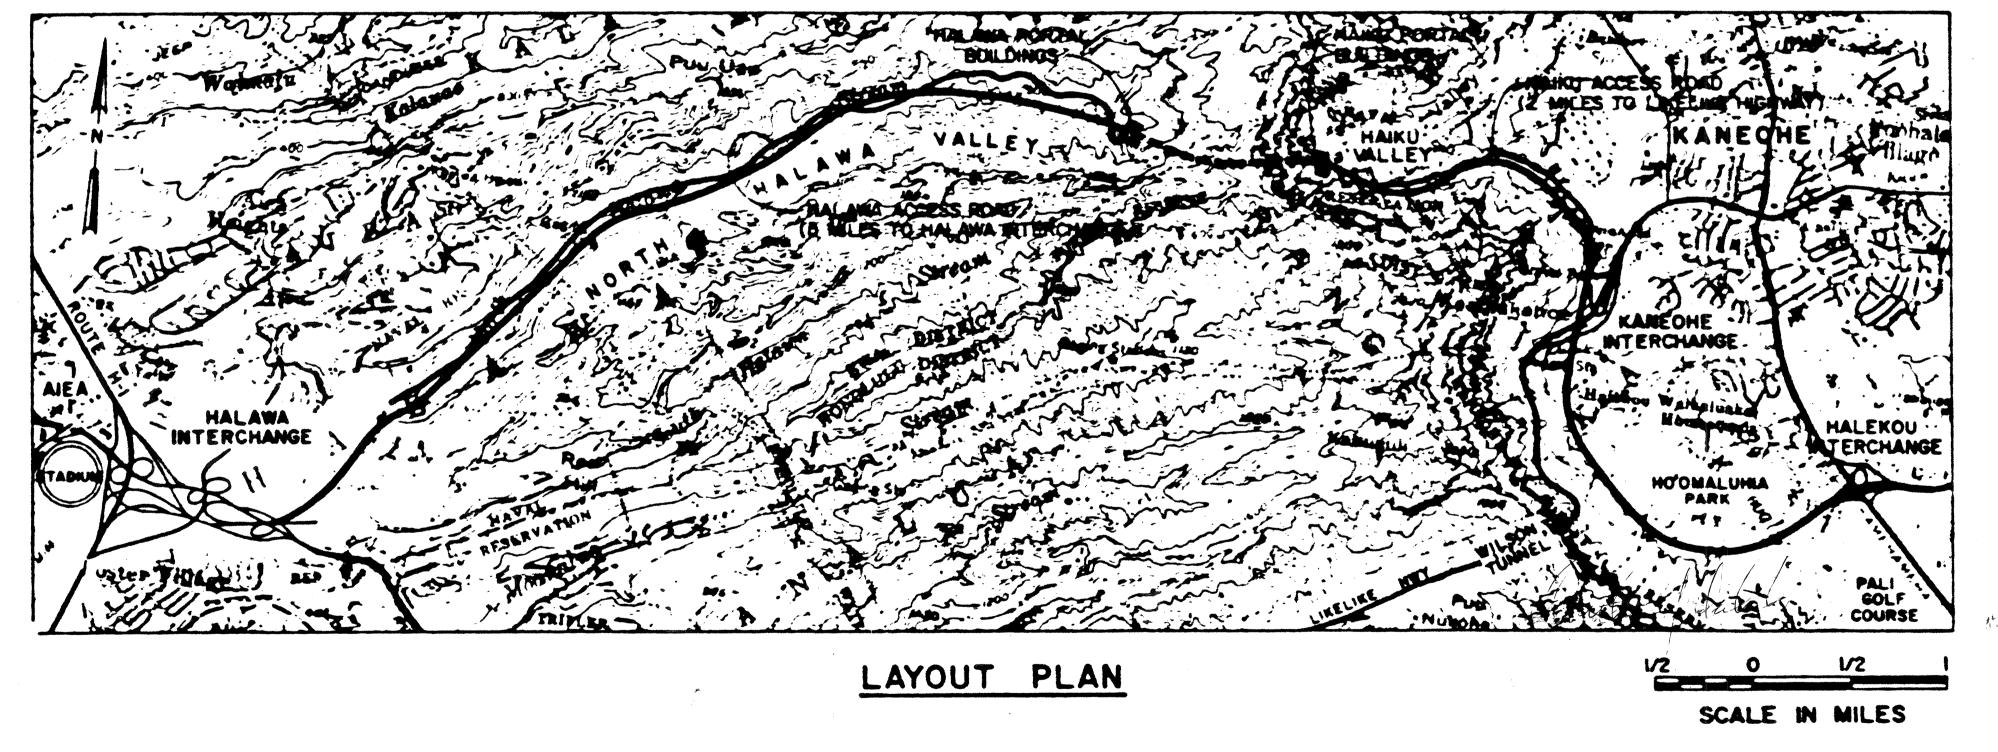

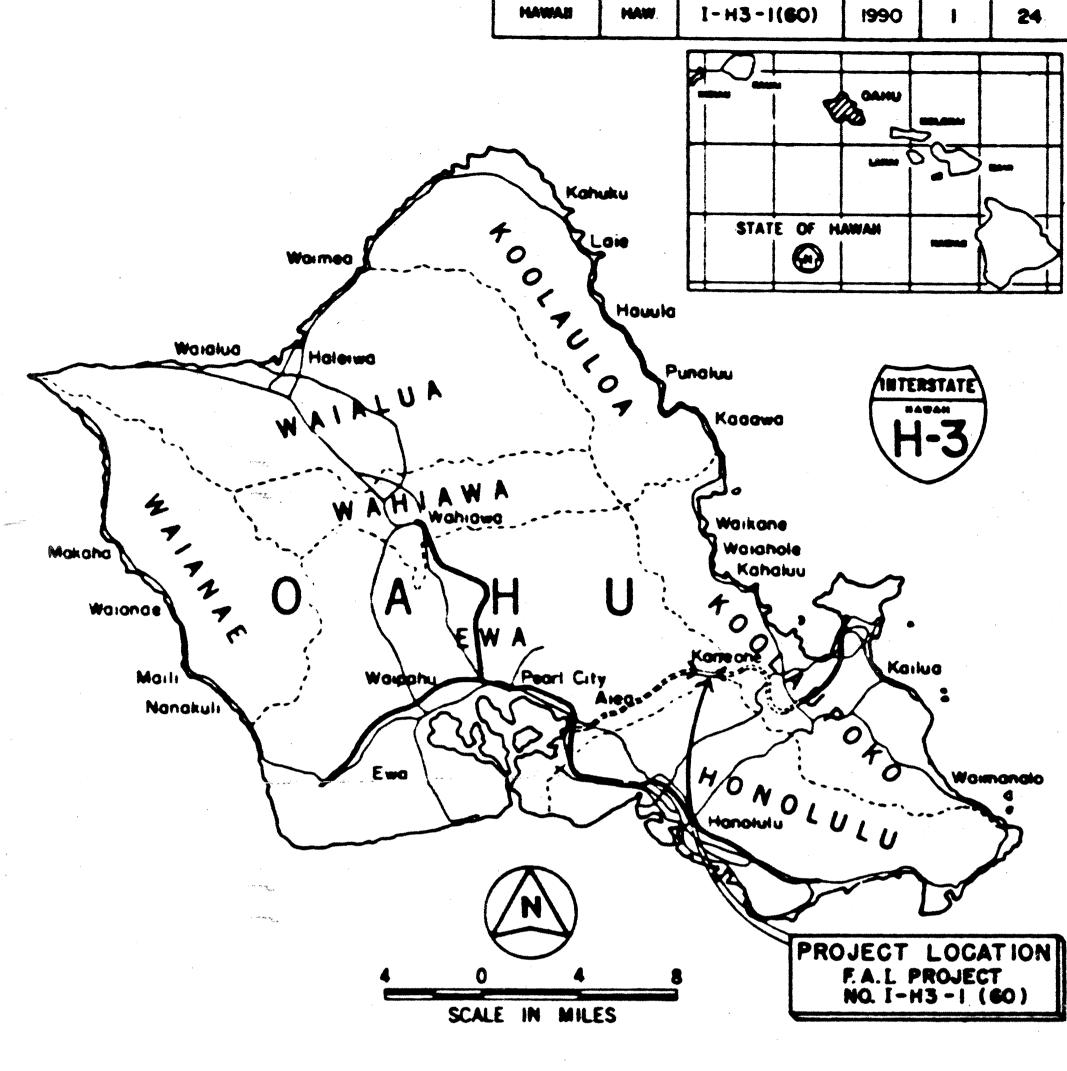

FED. ROAD DIST. NO.

CHANGES MADE DURING CONSTRUCTION HAVE BEEN INCORPORATED ON THESE PLANS EXCEPT CHANGES IN THE ORIGINAL THEORETICAL QUANTITIES, REFER TO PROJECT LEDGER AND/OR COMPUTATION BOOK.

RESIDENT ENGINEER

DATE

FISCAL SHEET TOTAL YEAR NO. SHEETS

FED. AID PROJ. NO.

DEPARTMENT OF TRANSPORTATION
FEDERAL HIGHWAY ADMINISTRATION

APPROVED
DIVISION ADMINISTRATOR

DATE

DEPARTMENT OF TRANSPORTATION
STATE OF HAWAII

APPROVED:

#/3/90
DIR. OF TRANSPORTATION DATE